



MODEL: ANODEL.ANAMES
FILE: \\nares-pw01\cso-bentley.com\pww01\Documents\DOT-Office\DrawH4-8\Project\ADB\FM67CADD\alca3\hrees\ADB\FM67\sh-sent.dgn

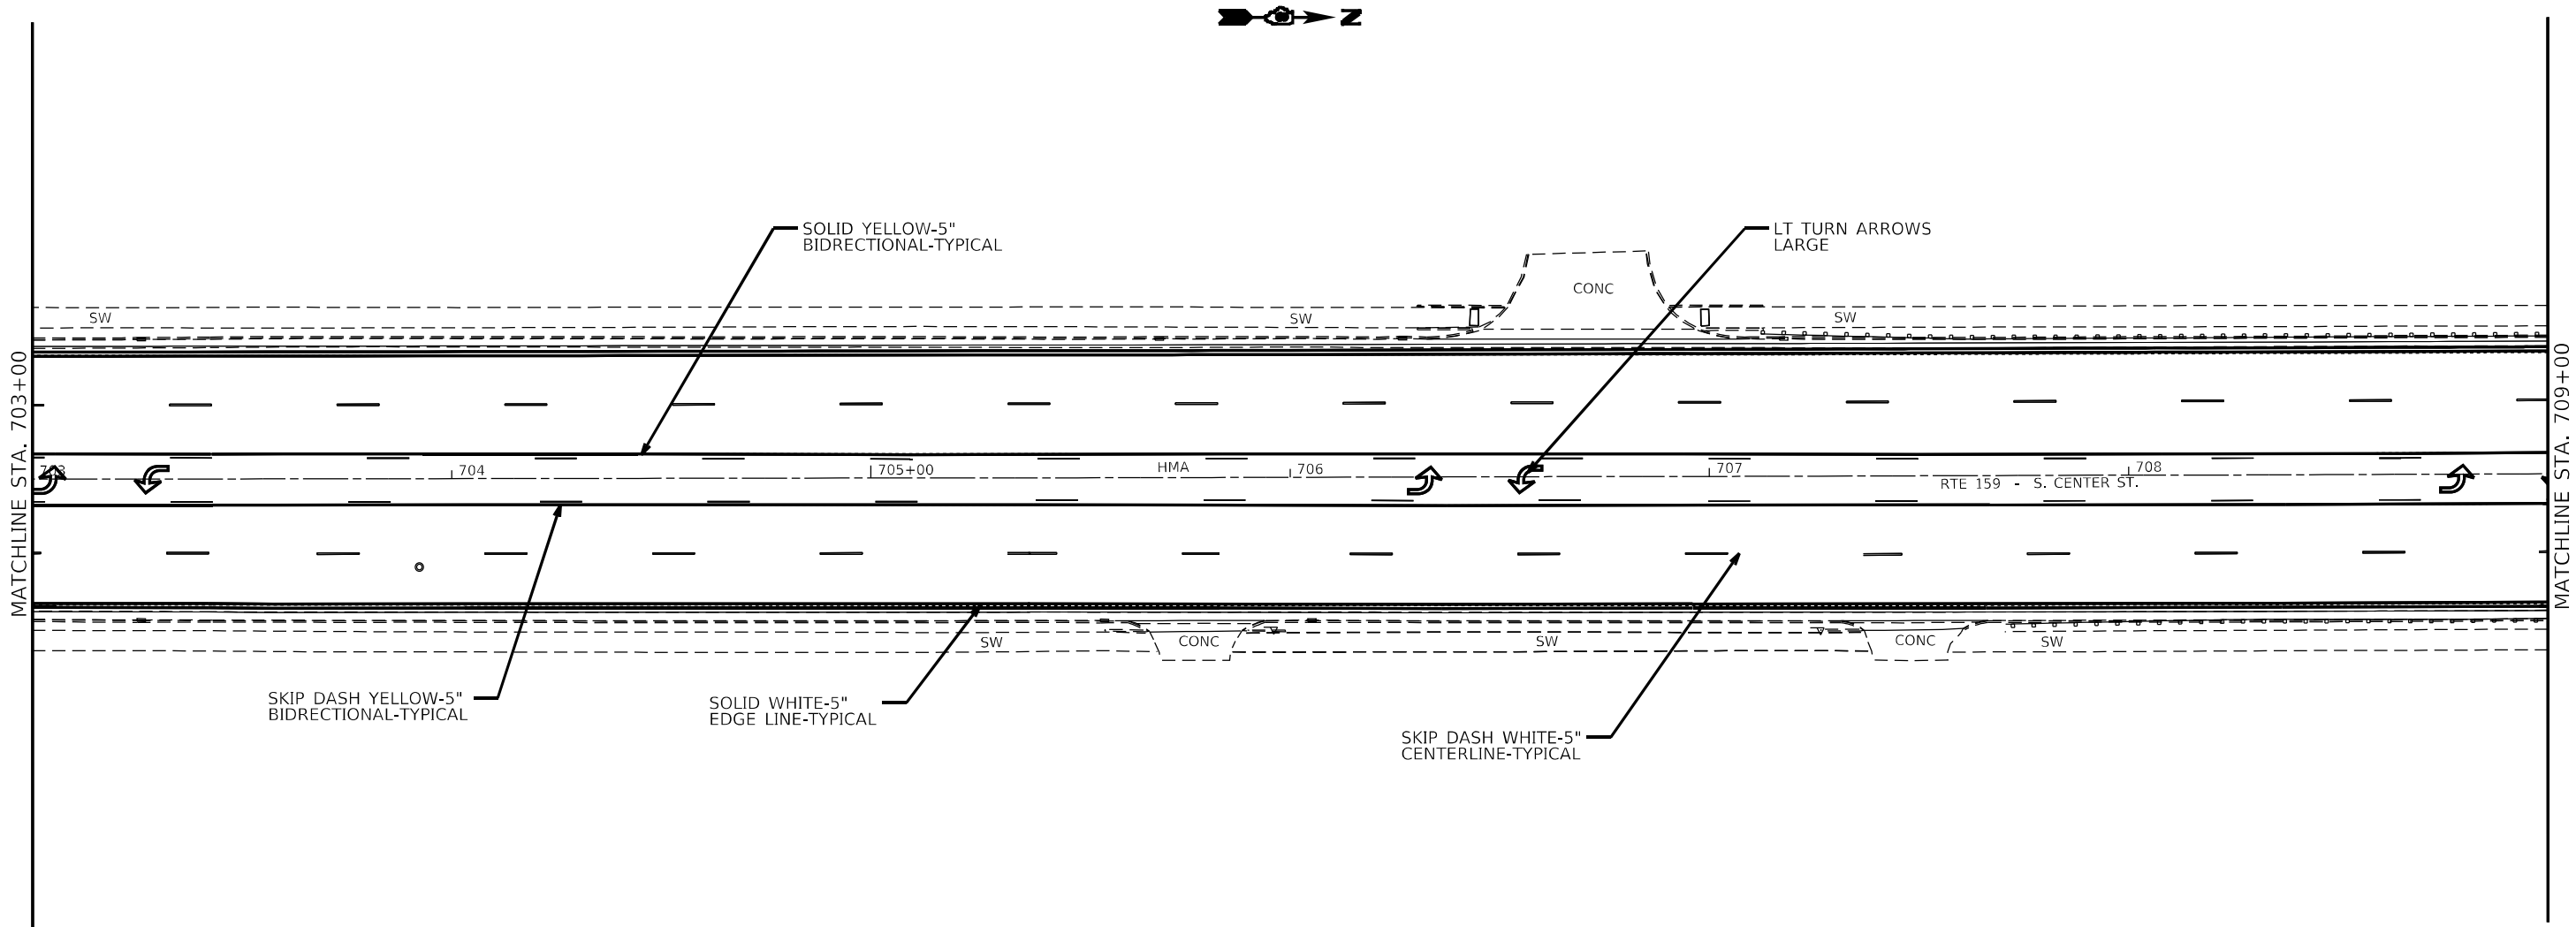

	USER NAME = edison.zonforyi	DESIGNED -	REVISED -	STATE OF ILLINOIS DEPARTMENT OF TRANSPORTATION	PAVEMENT MARKING				FAP/U RTE.	SECTION	COUNTY	TOTAL SHEETS	SHEET NO.	
		DRAWN -	REVISED -						*	(122,122-1,30)RS-4	MADISON	328	202	
	PLOT SCALE = 40,4587 ' / in.	CHECKED -	REVISED -		SCALE: 1:20				SHEET 22	OF 64	SHEETS	STA.	TO STA.	
	PLOT DATE = 10/26/2022	DATE -	REVISED -						ILLINOIS					FED. AID PROJECT
											CONTRACT NO. 76M87			

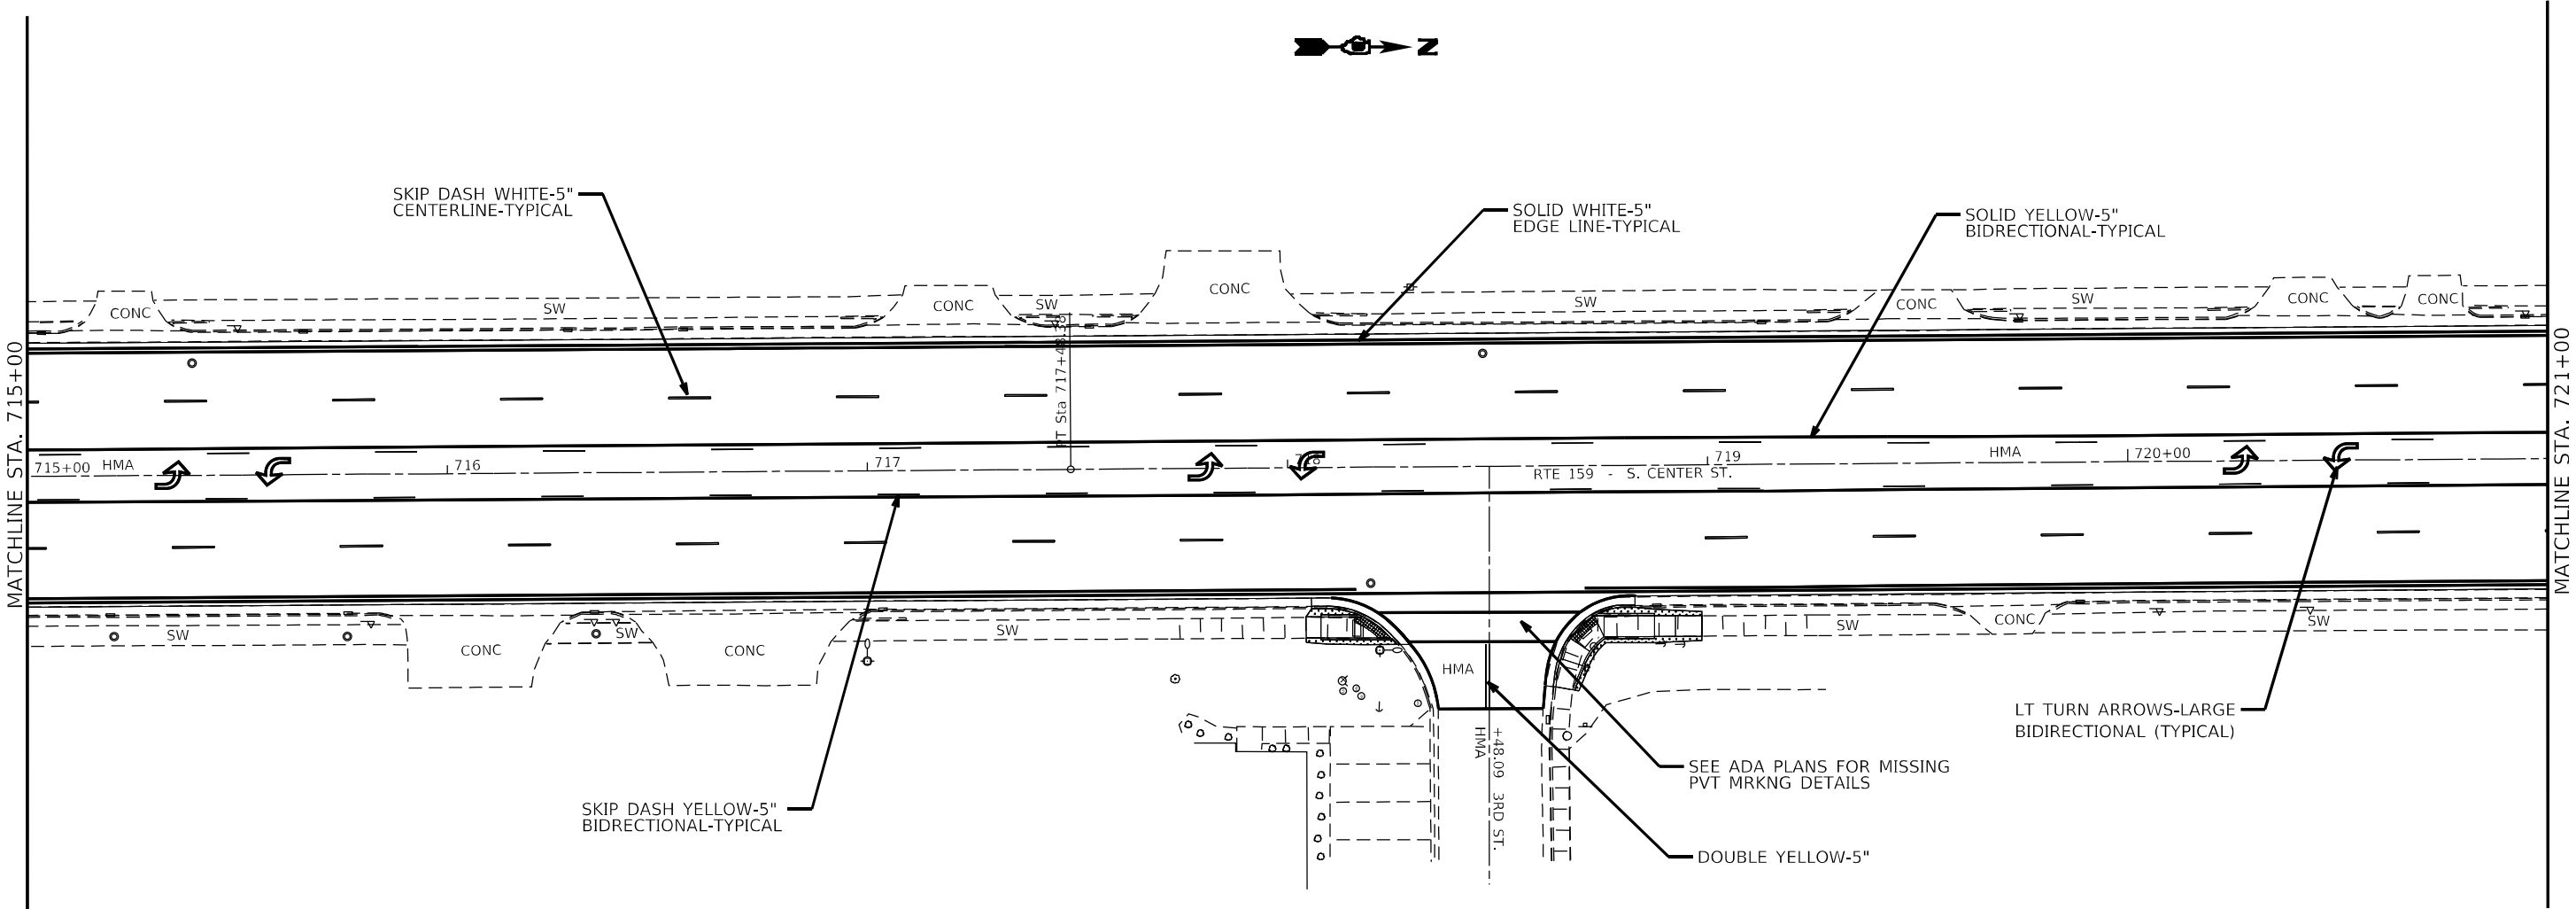

MODEL: ANODELX.MXS
FILE: \\na01\p01\benley.com\p01\DOT\Documents\DOT - Office\Draw44 - 81\Project\159\159MTCADD\159MTCADD.dwg
PLOT DATE: 10/26/2022


	USER NAME	= edison.zohforyi	DESIGNED	-	REVISED	-
	DRAWN	-	CHECKED	-	REVISED	-
	PLOT SCALE	= 40,4587 ' / in.	DATE	-	REVISED	-
	PLOT DATE	= 10/26/2022				

STATE OF ILLINOIS
DEPARTMENT OF TRANSPORTATION

PAVEMENT MARKING


SCALE: 1:20 SHEET 24 OF 64 SHEETS STA. TO STA.

FAP/U RTE.	SECTION	COUNTY	TOTAL SHEETS	SHEET NO.
*	(122,122-1,30)RS-4	MADISON	328	204
*600/8887		CONTRACT NO. 76M87		
ILLINOIS		FED. AID PROJECT		

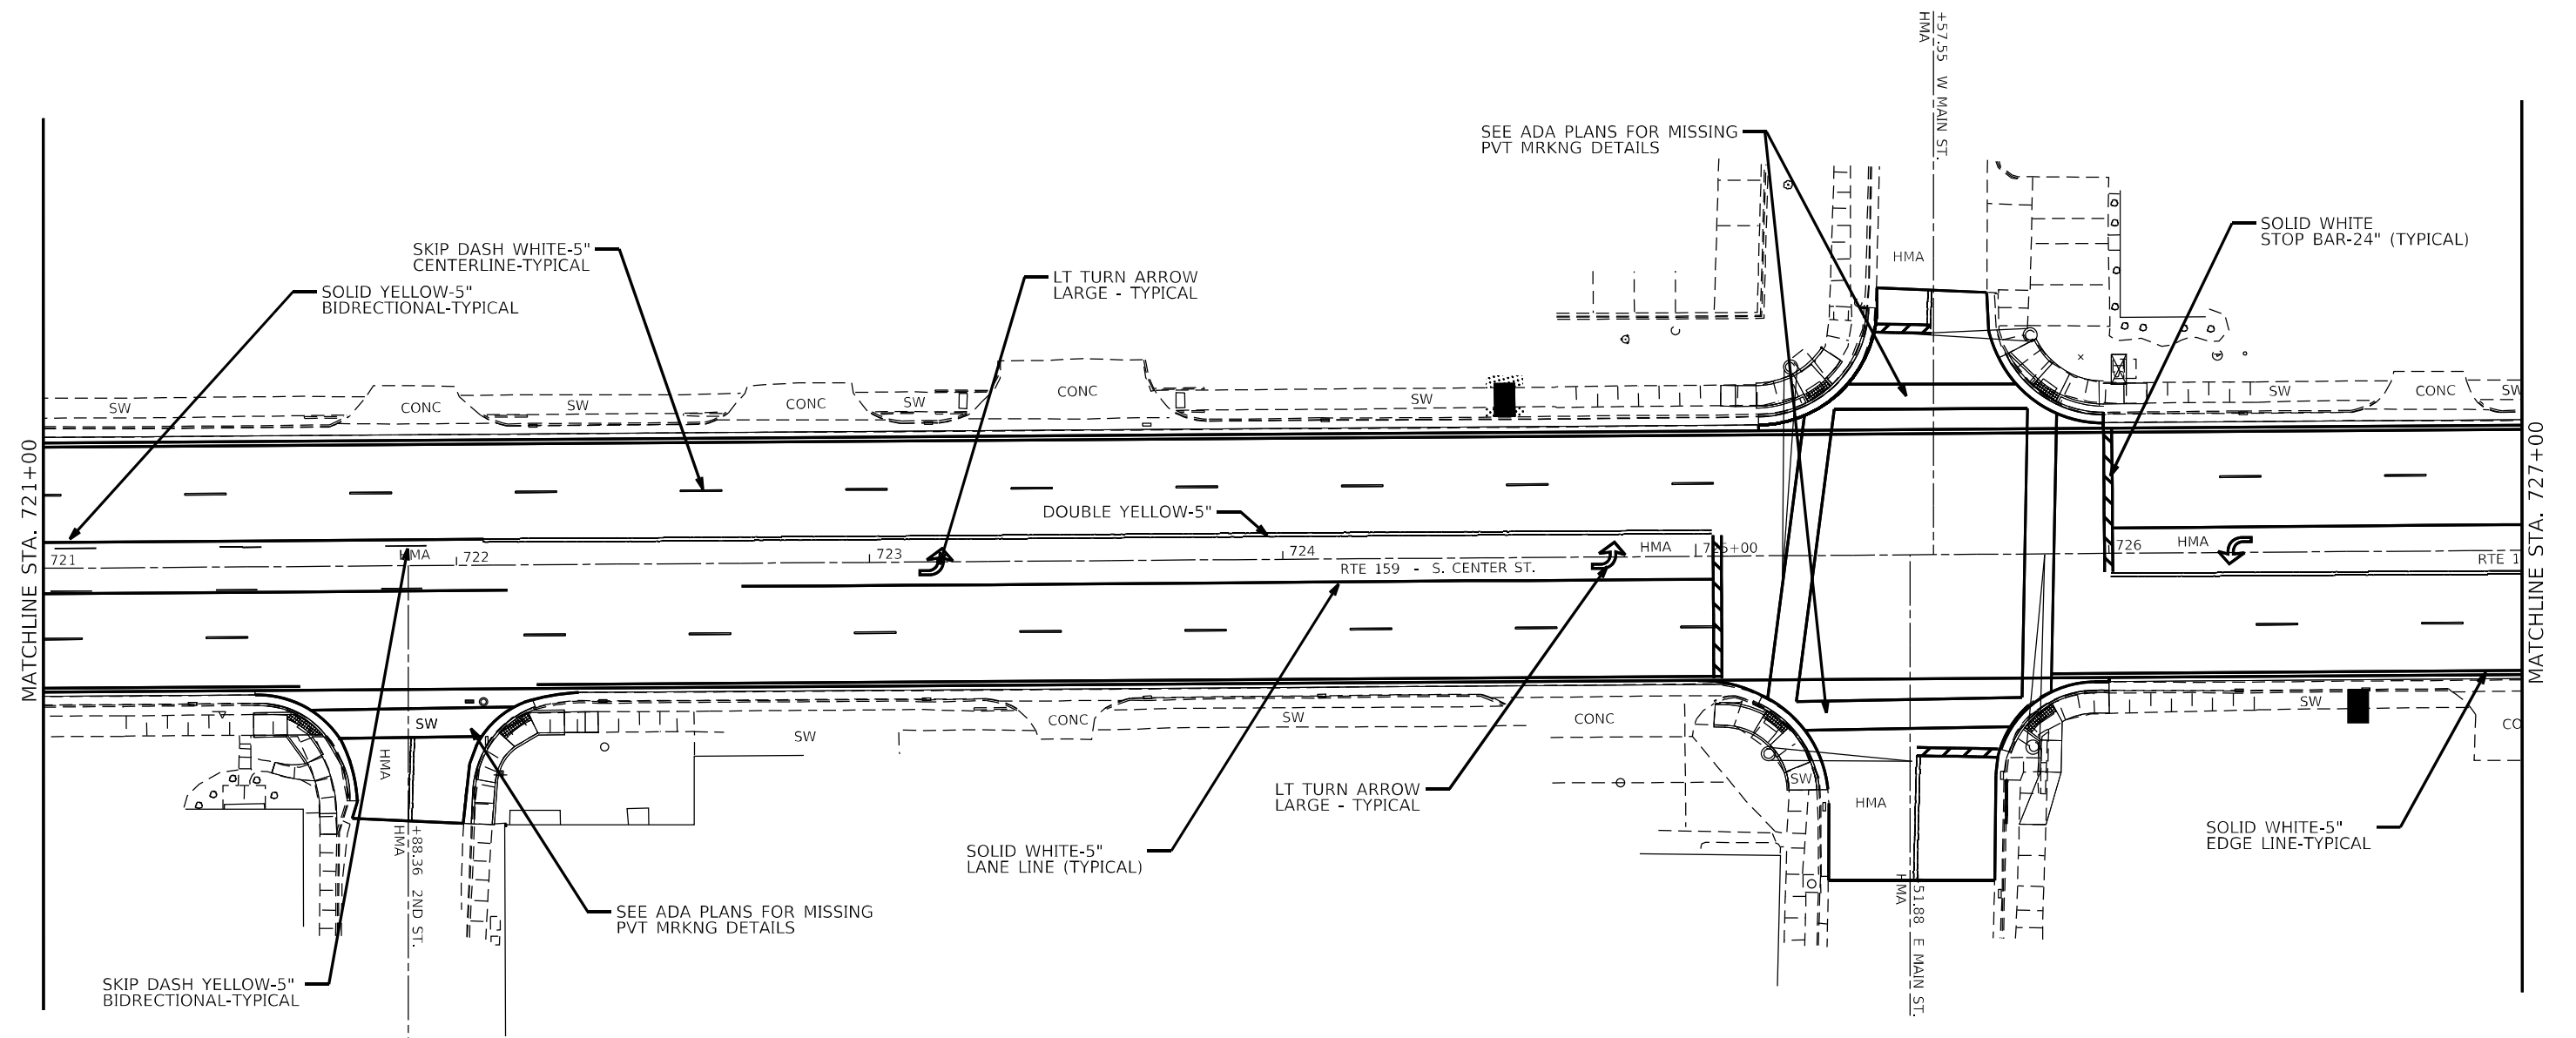

USER NAME = edison.zantonyi	DESIGNED -	REVISED -
	DRAWN -	REVISED -
PLOT SCALE = 40,4587 ' / in.	CHECKED -	REVISED -
PLOT DATE = 10/26/2022	DATE -	REVISED -

**STATE OF ILLINOIS
DEPARTMENT OF TRANSPORTATION**

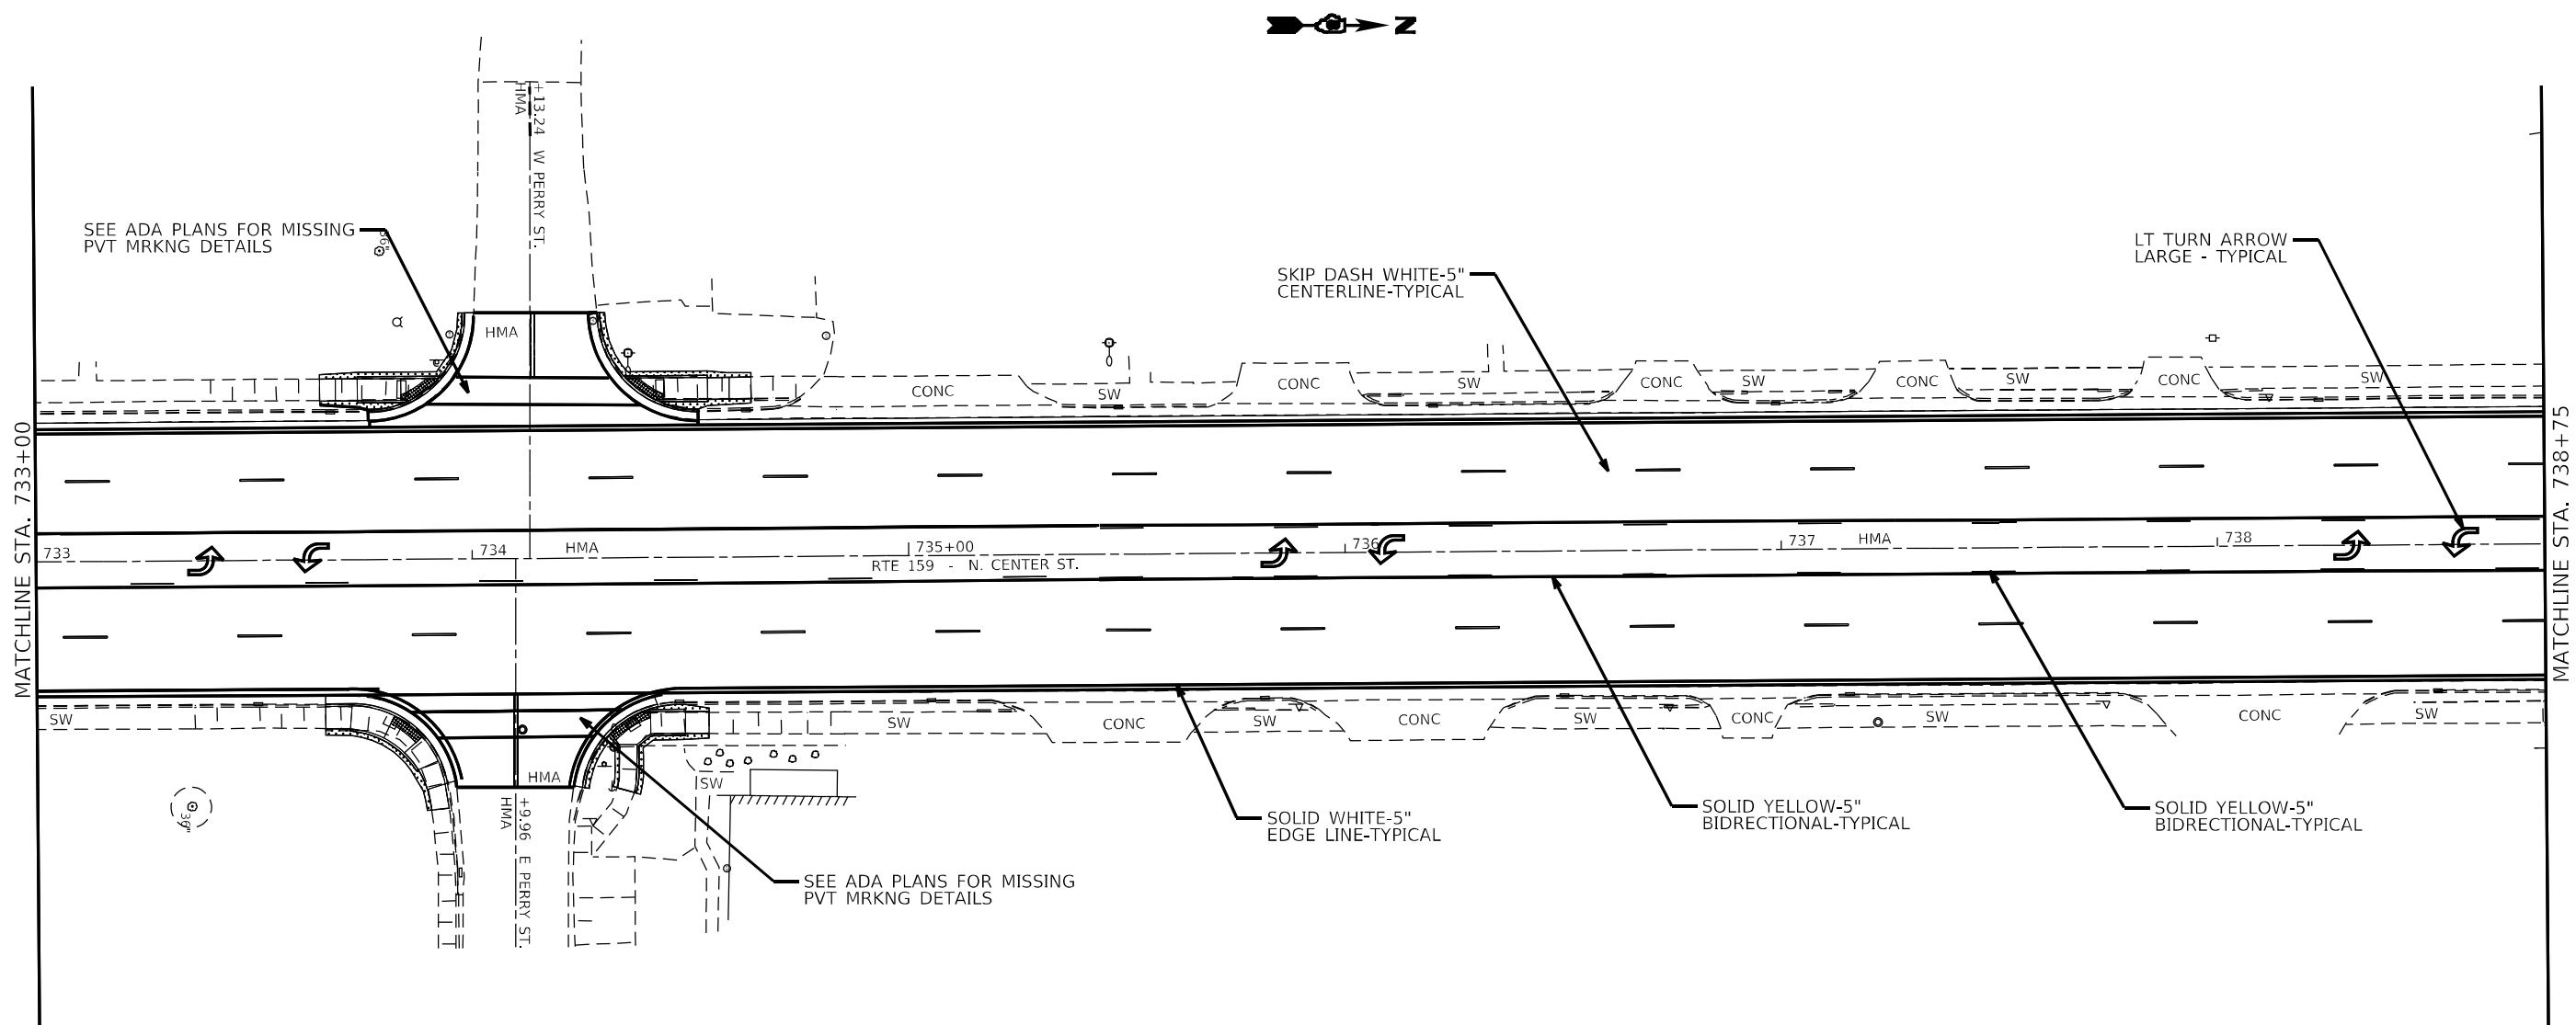


USER NAME = edison.zo@foryi	DESIGNED -	REVISED -
	DRAWN -	REVISED -
PLOT SCALE = 40,4587' / in.	CHECKED -	REVISED -
PLOT DATE = 10/26/2022	DATE -	REVISED -

**STATE OF ILLINOIS
DEPARTMENT OF TRANSPORTATION**

PAVEMENT MARKING

SCALE: 1:20	SHEET 27 OF 64 SHEETS	STA.	TO STA.
-------------	-----------------------	------	---------

FAP/U RTE.	SECTION	COUNTY	TOTAL SHEETS	SHEET NO.
*	(122,122-1,30)R5-4	MADISON	328	207
*600/8887		CONTRACT NO. 76M87		
	ILLINOIS	FED. AID PROJECT		

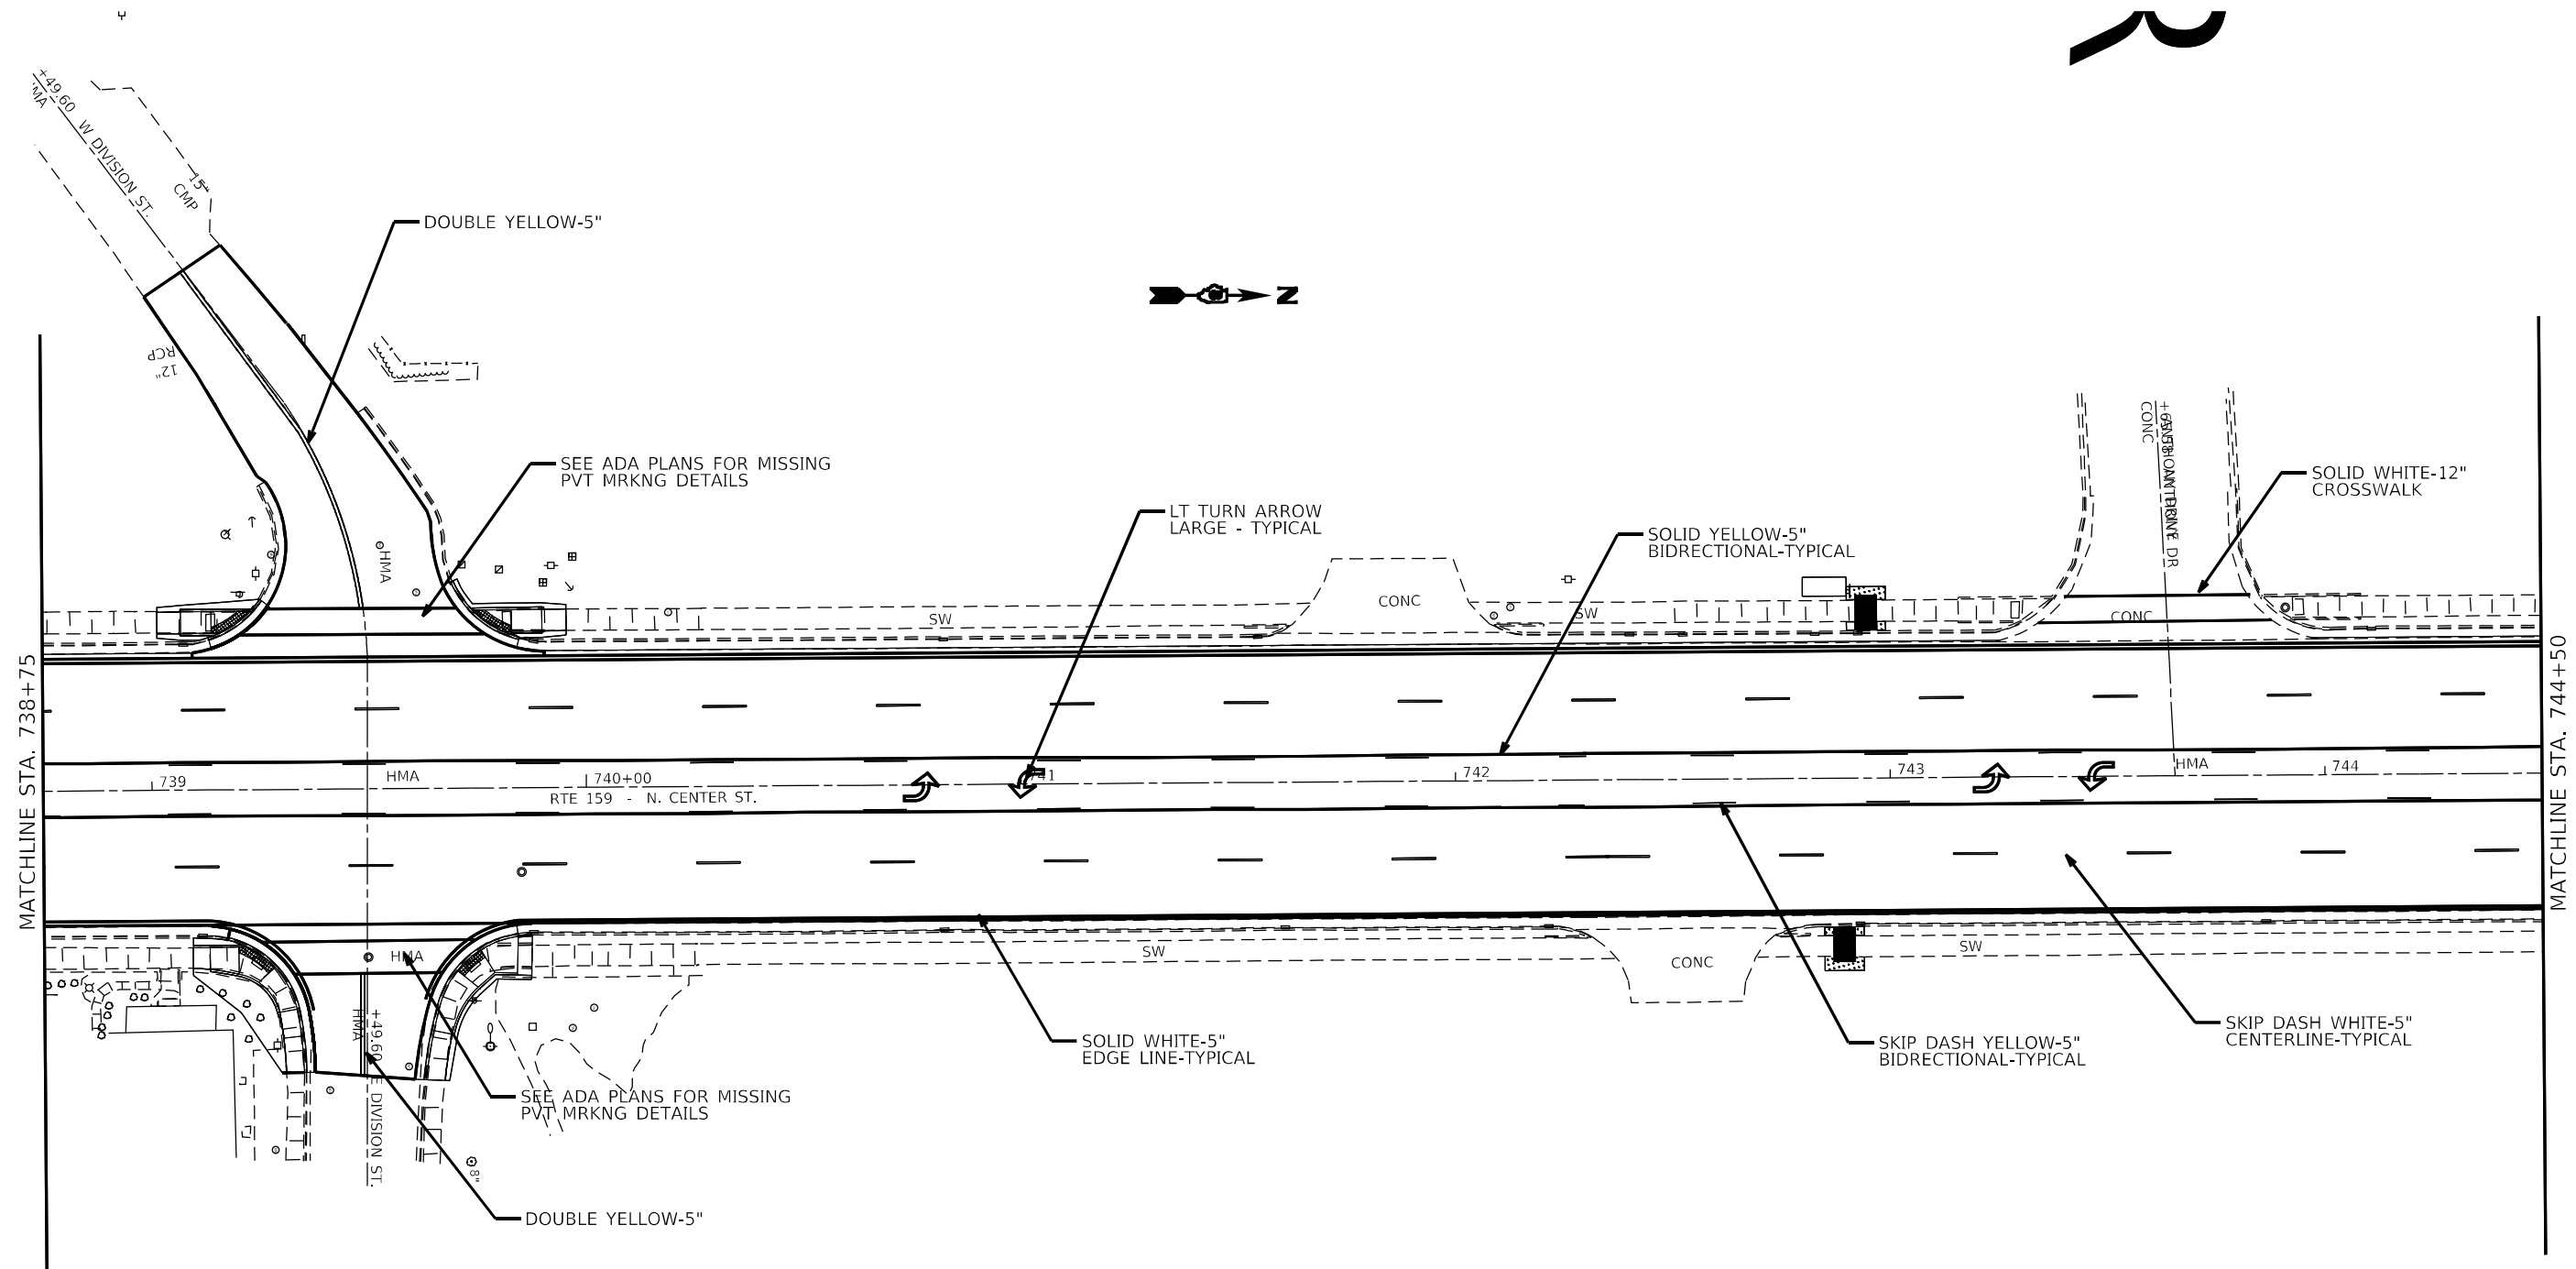


USER NAME = edison.zo@foryi	DESIGNED -	REVISED -
	DRAWN -	REVISED -
PLOT SCALE = 40,4587' / in.	CHECKED -	REVISED -
PLOT DATE = 10/26/2022	DATE -	REVISED -

STATE OF ILLINOIS
DEPARTMENT OF TRANSPORTATION

PAVEMENT MARKING


SCALE: 1:20	SHEET 28 OF 64 SHEETS	STA.	TO STA.
-------------	-----------------------	------	---------

FAP/U RTE.	SECTION	COUNTY	TOTAL SHEETS	SHEET NO.
*	(122,122-1,30)RS-4	MADISON	328	208
*600/8887		CONTRACT NO. 76M87		
		ILLINOIS	FED. AID PROJECT	

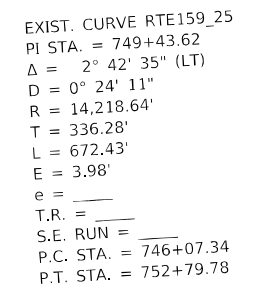


FAP/J RTE.	SECTION	COUNTY	TOTAL SHEETS	SHEET NO.
*	(122,122-1,30)RS-4	MADISON	328	209
*600/8887		CONTRACT NO. 76M87		
	ILLINOIS	FED. AID PROJECT		

MODEL: ANODELX.MXS
FILE: \\nares-pc\illinois\bailey.com\DWG\DOT\Documents\DOT_Office\Drawn\4. 8\Project\ADB\6M67\CAD\Data\CAD\Sheet\ADB\6M67\6M67-211-001.dwg

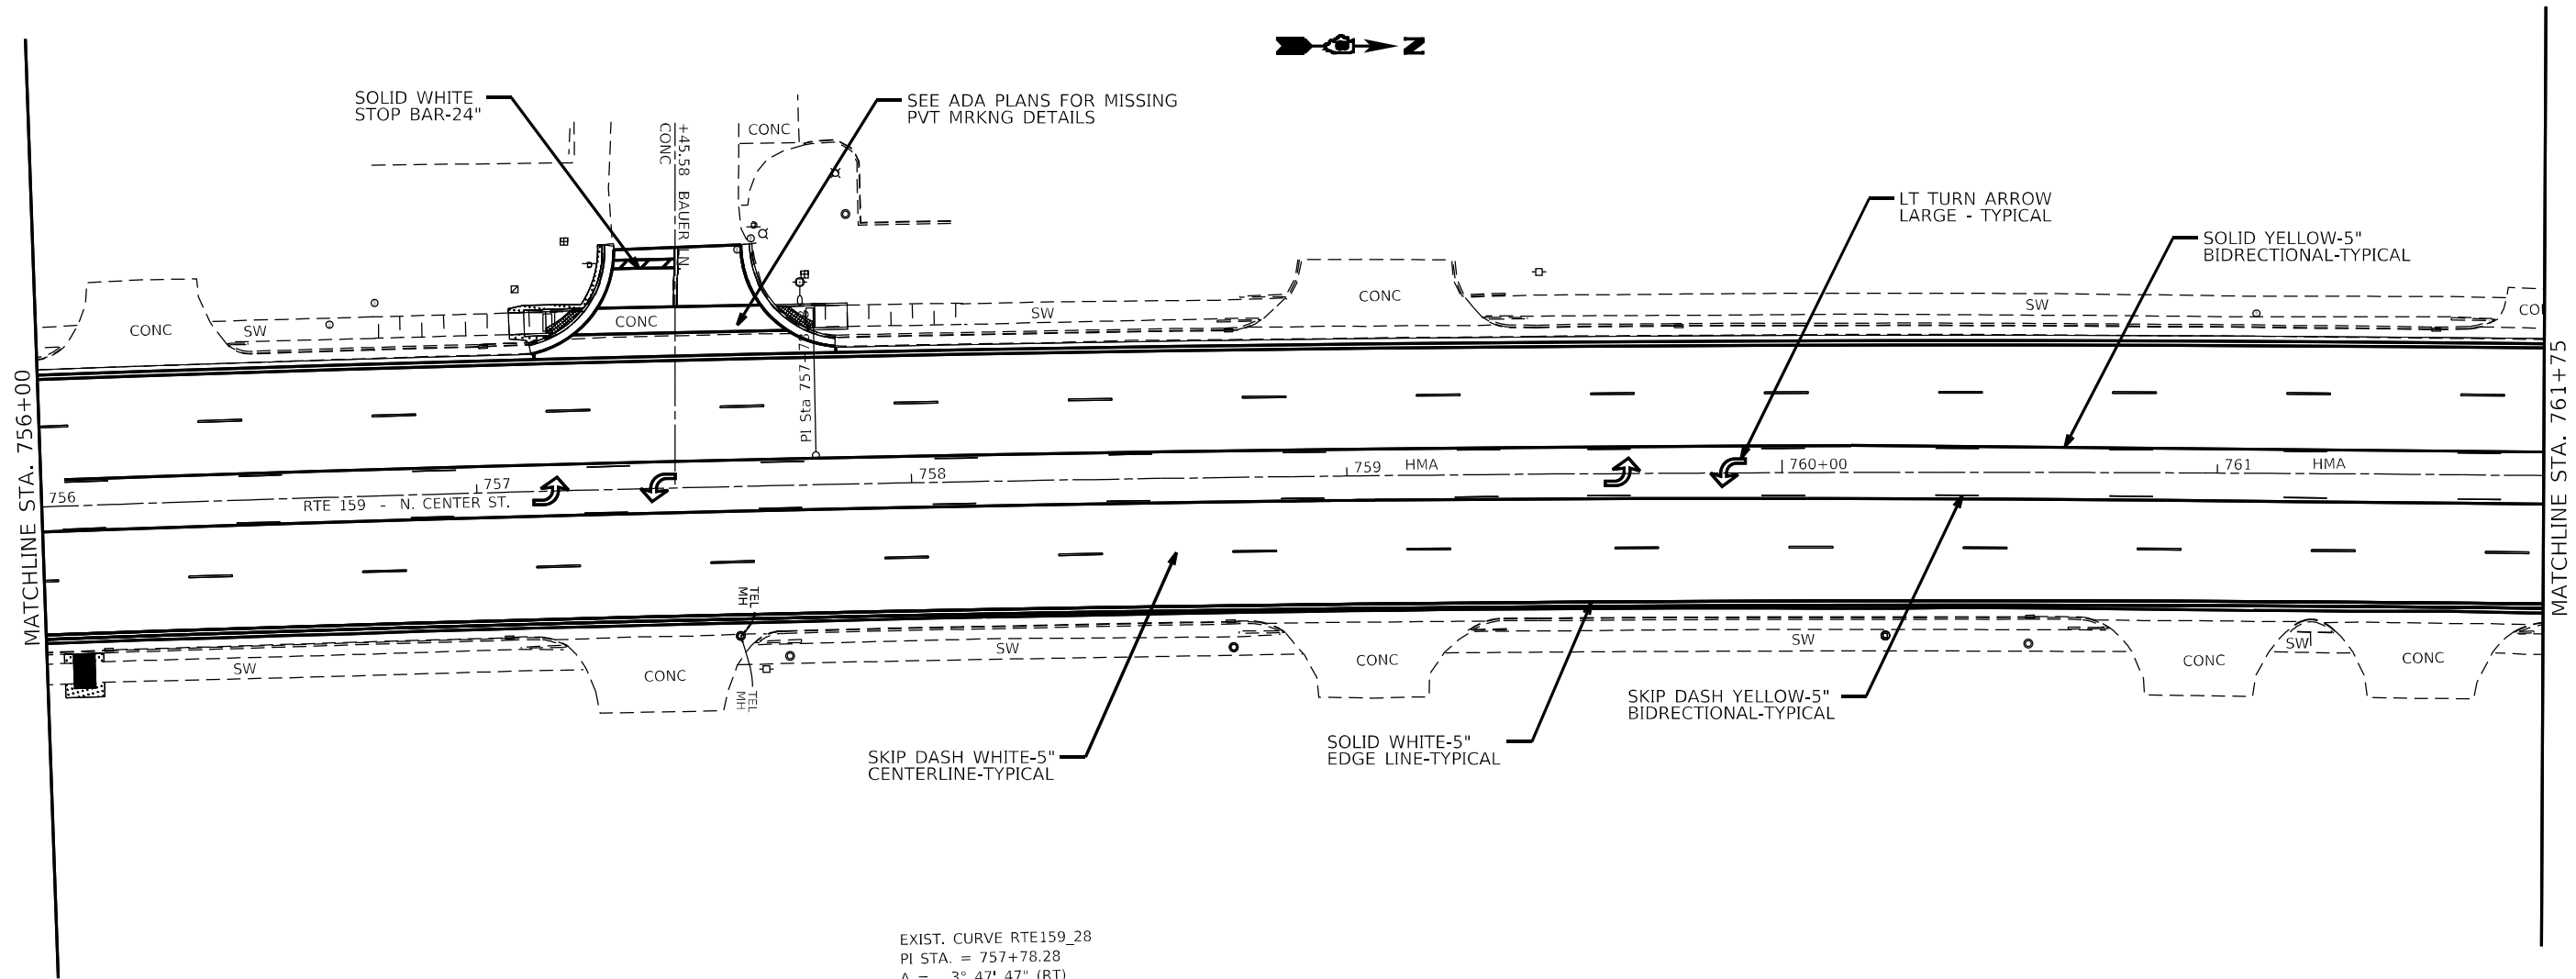

EXIST. CURVE RTE159_28
PI STA. = 757+78.28
 Δ = 3° 47' 47" (RT)
D = 0° 27' 58"
R = 12,288.69'
T = 407.27'
L = 814.24'
E = 6.75'
e = ____
T.R. = ____
S.E. RUN = ____
P.C. STA. = 753+71.01
P.T. STA. = 761+85.25

	USER NAME = edison.zohforyi	DESIGNED -	REVISED -	STATE OF ILLINOIS DEPARTMENT OF TRANSPORTATION	PAVEMENT MARKING				FAP/U RTE.	SECTION	COUNTY	TOTAL SHEETS	SHEET NO.
		DRAWN -	REVISED -						*	(122,122-1,30)/RS-4	MADISON	328	211
	PLOT SCALE = 40,4587' / in.	CHECKED -	REVISED -		SCALE: 1:20				CONTRACT NO. 76M87				
	PLOT DATE = 10/26/2022	DATE -	REVISED -		SHEET 31	OF 64	SHEETS	STA.	TO STA.	ILLINOIS FED. AID PROJECT			

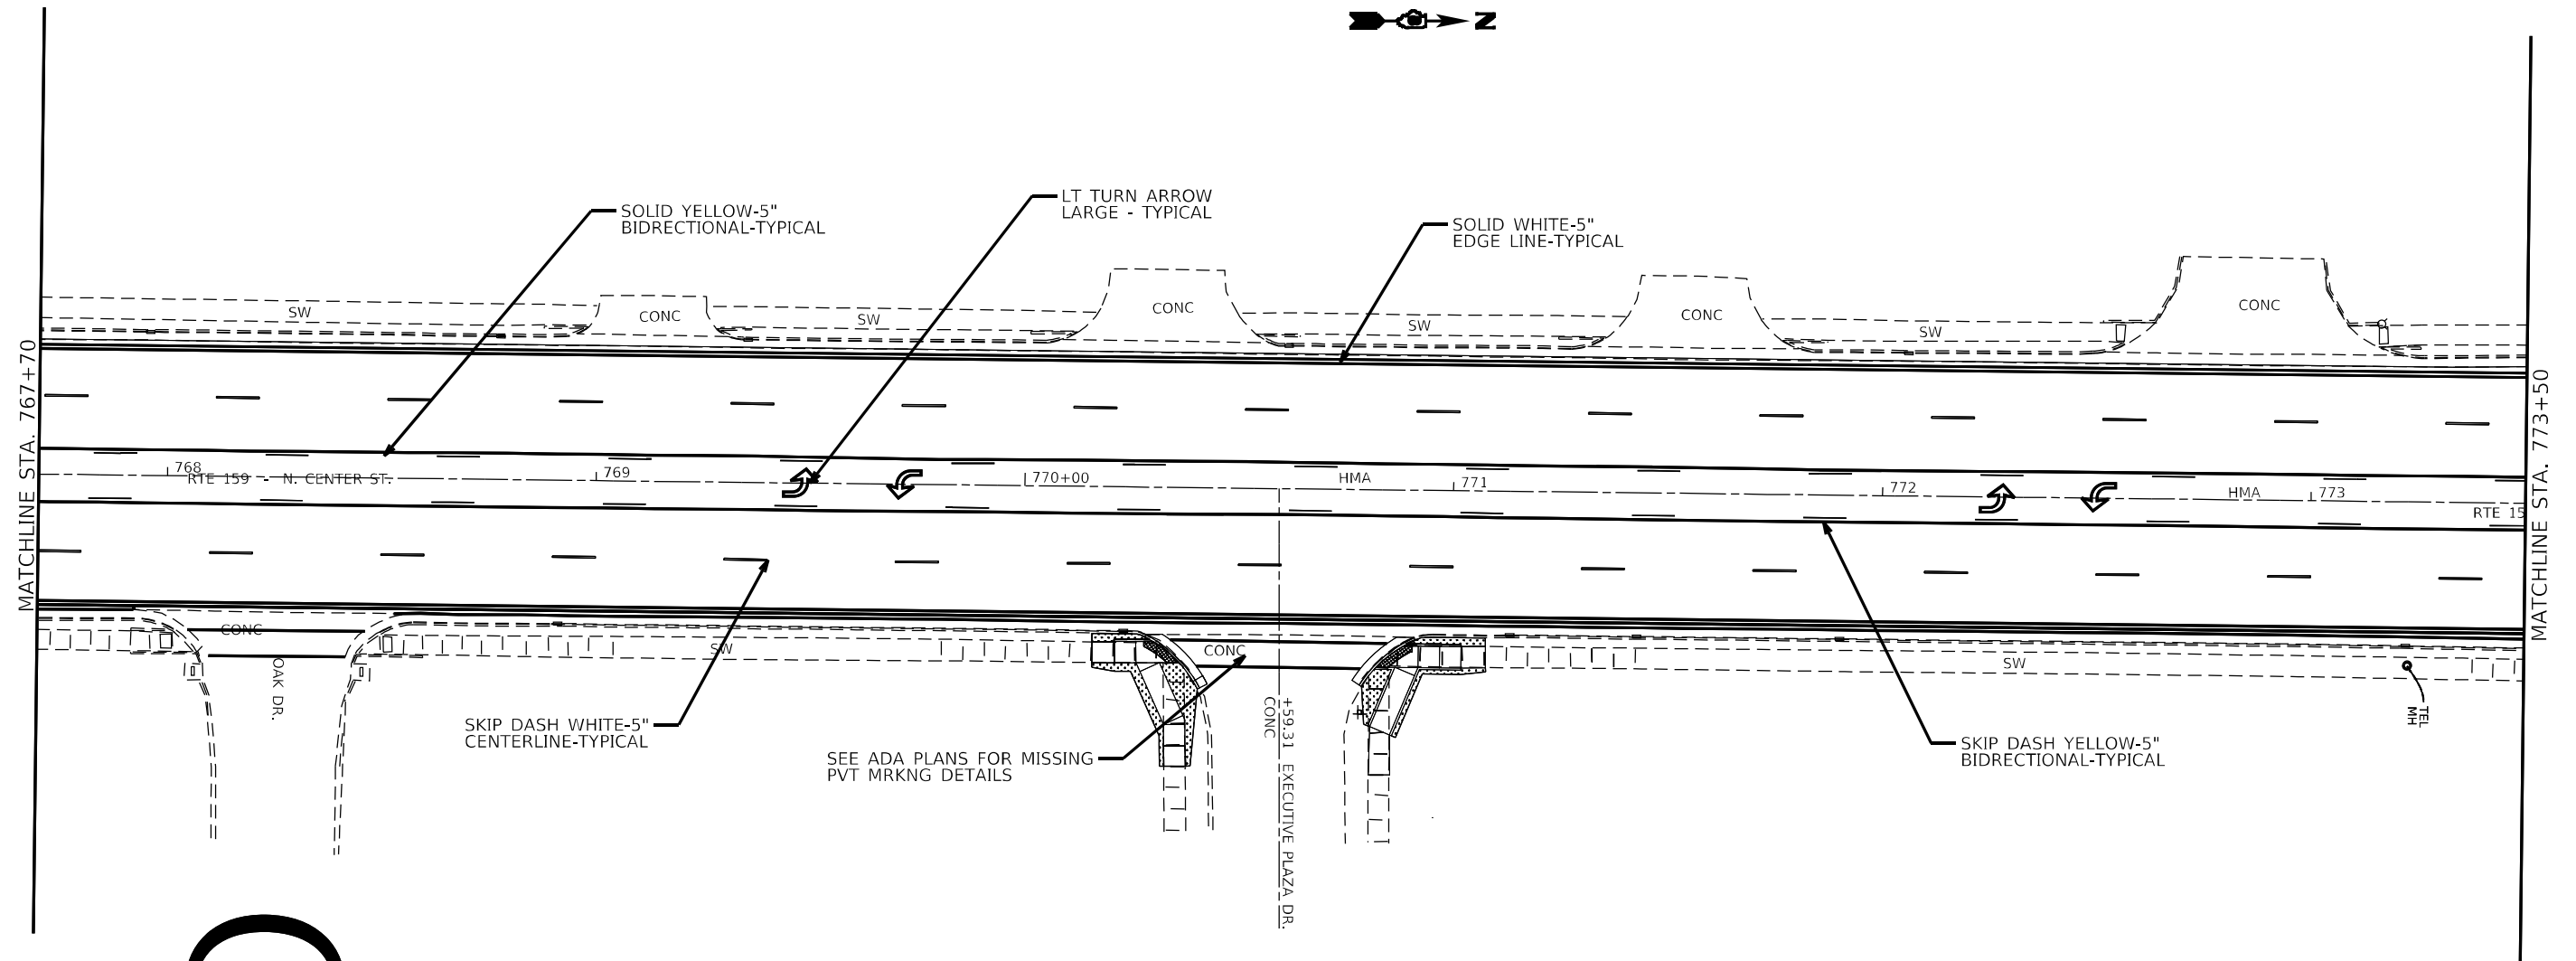

FILE NAME: 100	USER NAME = edison.zo@foryl	DESIGNED -	REVISED -	STATE OF ILLINOIS DEPARTMENT OF TRANSPORTATION	PAVEMENT MARKING				FAP/U RTE.	SECTION	COUNTY	TOTAL SHEETS	SHEET NO.
		DRAWN -	REVISED -						=	(122,122-1,30)R5-4	MADISON	328	213
	PLOT SCALE = 40,4587' / in.	CHECKED -	REVISED -		#600/8887	CONTRACT NO. 76M87							
	PLOT DATE = 10/26/2022	DATE -	REVISED -		SCALE: 1:20	SHEET 33	OF 64 SHEETS	STA.	TO STA.				




STATE OF ILLINOIS
DEPARTMENT OF TRANSPORTATION

SCALE: 1:20	SHEET 34 OF 64 SHEETS	STA.	TO STA.
-------------	-----------------------	------	---------

FAP/J RTE.	SECTION	COUNTY	TOTAL SHEETS	SHEET NO.
*	(122,122-1,30)R5-4	MADISON	328	214
*600/8887		CONTRACT NO. 76M87		
		ILLINOIS	FED. AID PROJECT	

MODEL - ANODEL.ANAMES
FILE - \\nares-pc01\usps-bentley.com\pwwid01\Documents\DOT - Office\Draw14 - 81\Project\1408\FM07\CADD\03\Sheet\03.DWG\FM07-241b-pmk1.dgn

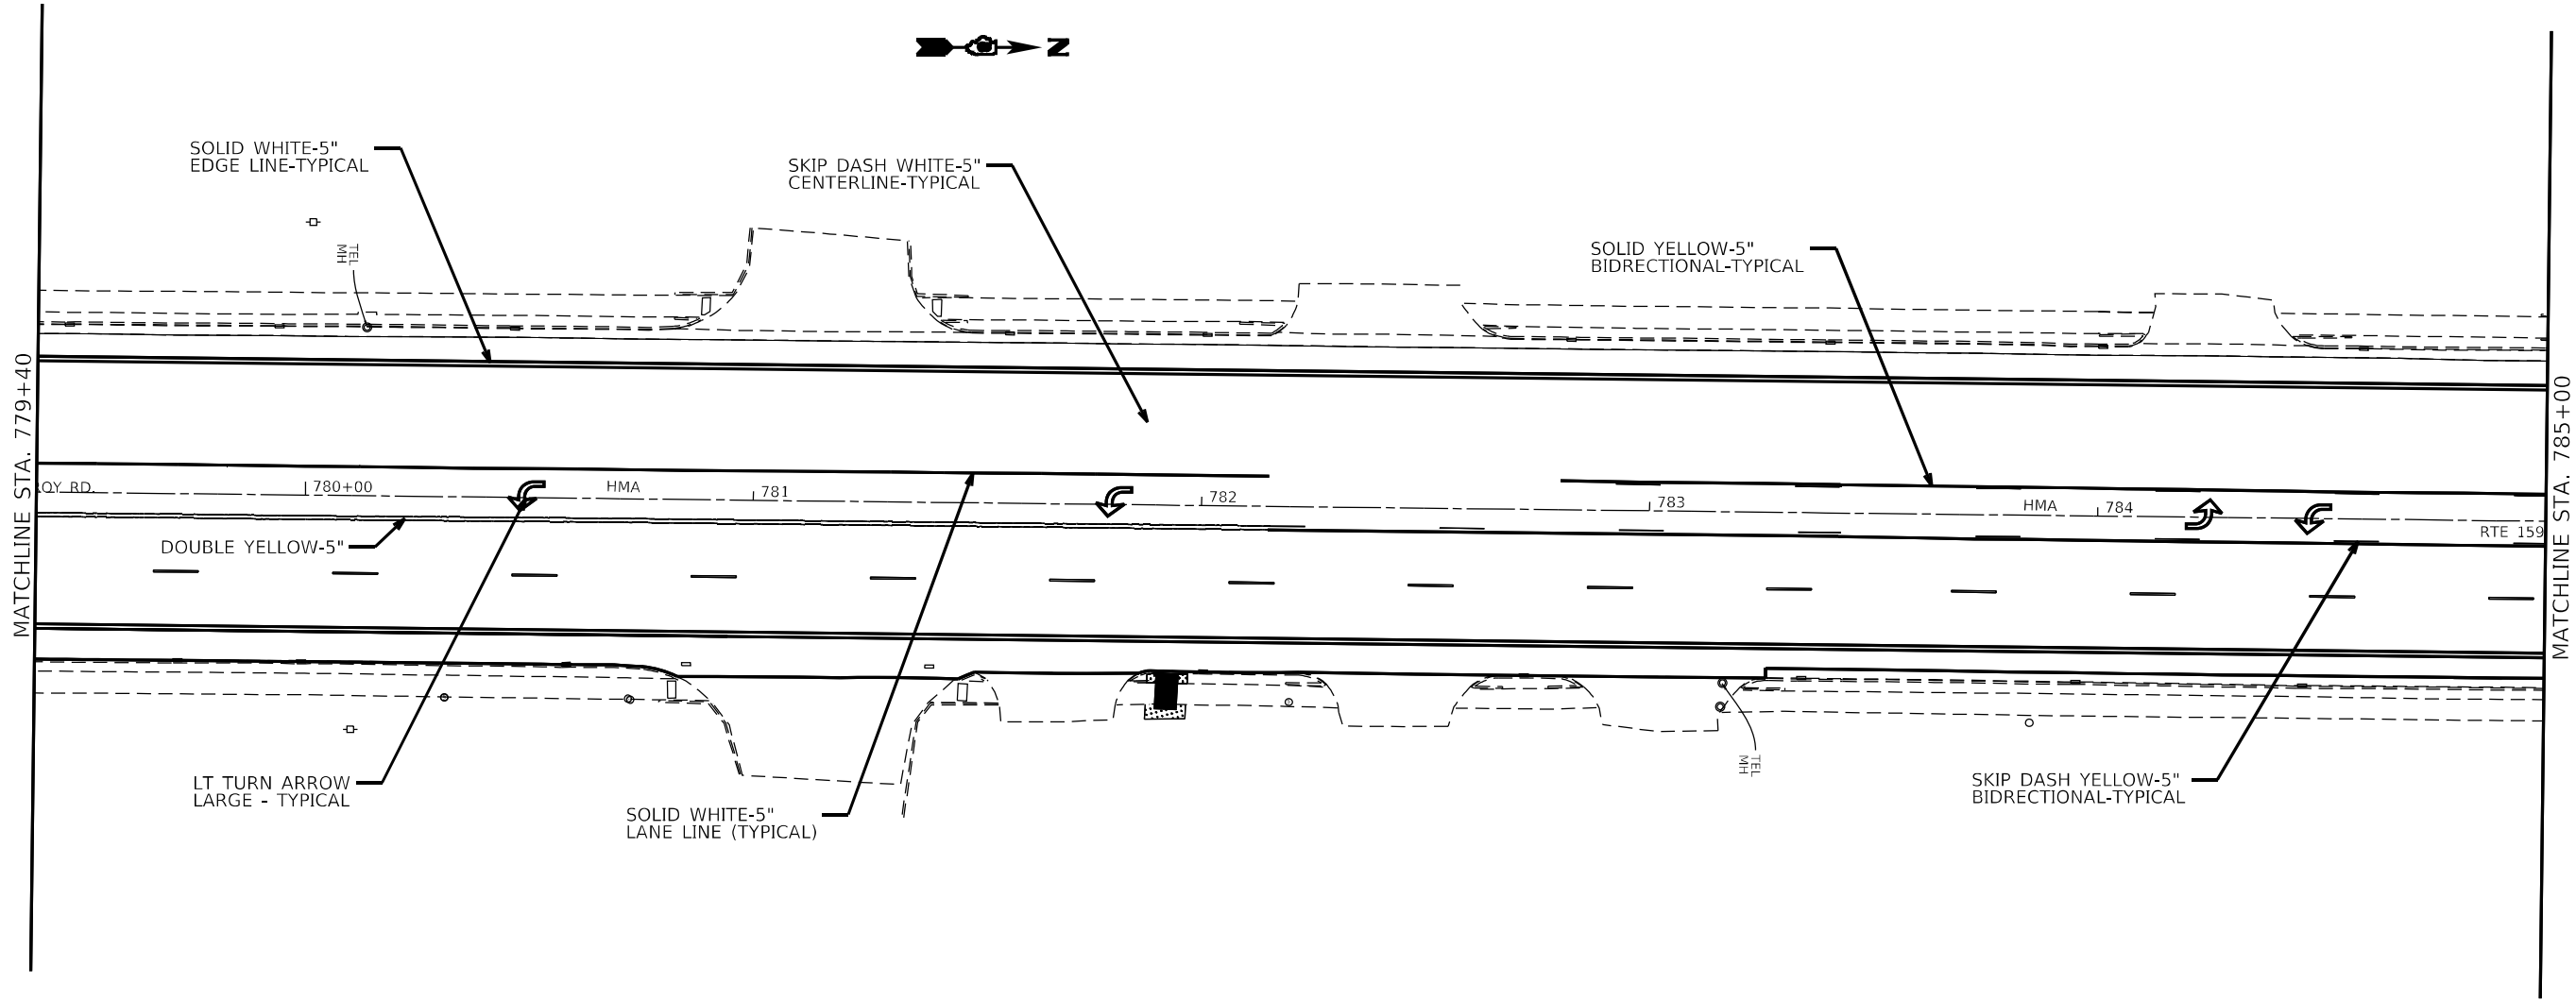


	USER NAME	= edison.zohforyi	DESIGNED	-	REVISED	-
			DRAWN	-	REVISED	-
	PLOT SCALE	= 40,4587 ' / in.	CHECKED	-	REVISED	-
	PLOT DATE	= 10/26/2022	DATE	-	REVISED	-

STATE OF ILLINOIS
DEPARTMENT OF TRANSPORTATION

PAVEMENT MARKING

SCALE: 1:20 SHEET 35 OF 64 SHEETS STA. TO STA.

FAP/U RTE.	SECTION	COUNTY	TOTAL SHEETS	SHEET NO.
*	(122,122-1,30)/RS-4	MADISON	328	215
*600/8887		CONTRACT NO. 76M87		
		ILLINOIS	FED. AID PROJECT	

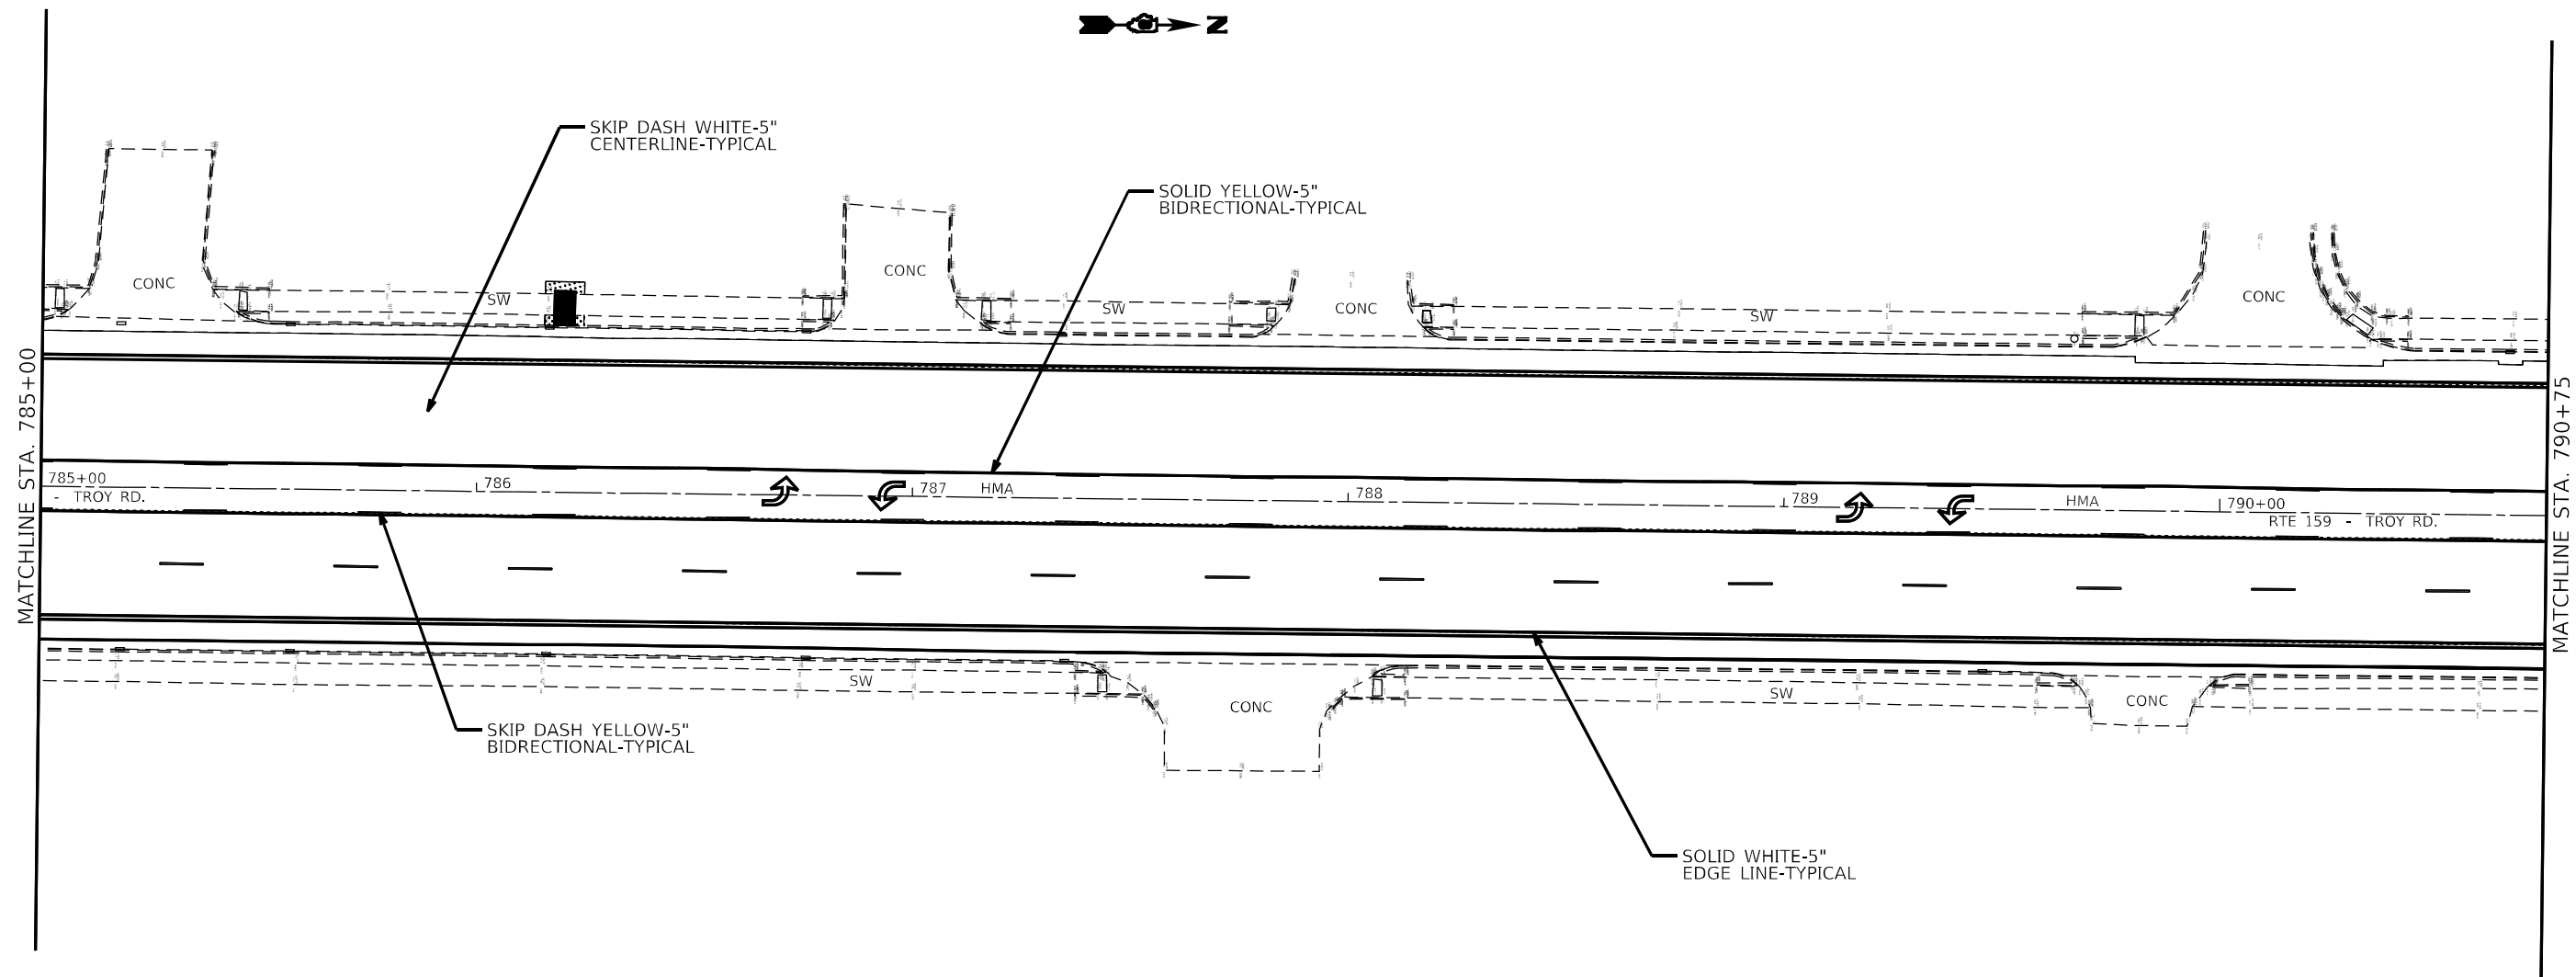

USER NAME = edison.zohforoyi	DESIGNED -	REVISED -
	DRAWN -	REVISED -
PLOT SCALE = 40,4587' / in.	CHECKED -	REVISED -
PLOT DATE = 10/26/2022	DATE -	REVISED -

**STATE OF ILLINOIS
DEPARTMENT OF TRANSPORTATION**

PAVEMENT MARKING

SCALE: 1:20	SHEET 36 OF 64 SHEETS	STA.	TO STA.
-------------	-----------------------	------	---------

FAP/U RTE.	SECTION	COUNTY	TOTAL SHEETS	SHEET NO.
*	(122,122-1,30)R5-4	MADISON	328	216
*600/8887		CONTRACT NO. 76M87		
ILLINOIS		FED. AID PROJECT		




FILE NAME: 1001	USER NAME = edison.zo@foryl	DESIGNED -	REVISED -	STATE OF ILLINOIS DEPARTMENT OF TRANSPORTATION	PAVEMENT MARKING				FAP/U RTE.	SECTION	COUNTY	TOTAL SHEETS	SHEET NO.
		DRAWN -	REVISED -						=	(122,122-1,30)R5-4	MADISON	328	217
	PLOT SCALE = 40,4587' / in.	CHECKED -	REVISED -		600/8887				CONTRACT NO. 76M87				
	PLOT DATE = 10/26/2022	DATE -	REVISED -		SCALE: 1:20	SHEET 37	OF 64 SHEETS	STA. TO STA.					



SKIP DASH WHITE-5" —
CENTERLINE-TYPICAL


STATE OF ILLINOIS
DEPARTMENT OF TRANSPORTATION

FAP/UP RTE.	SECTION	COUNTY	TOTAL SHEETS	SHEET NO.
*	(122,122-1,30)RS-4	MADISON	328	220
*600/8887		CONTRACT NO. 76M87		
	ILLINOIS	FED. AID PROJECT		

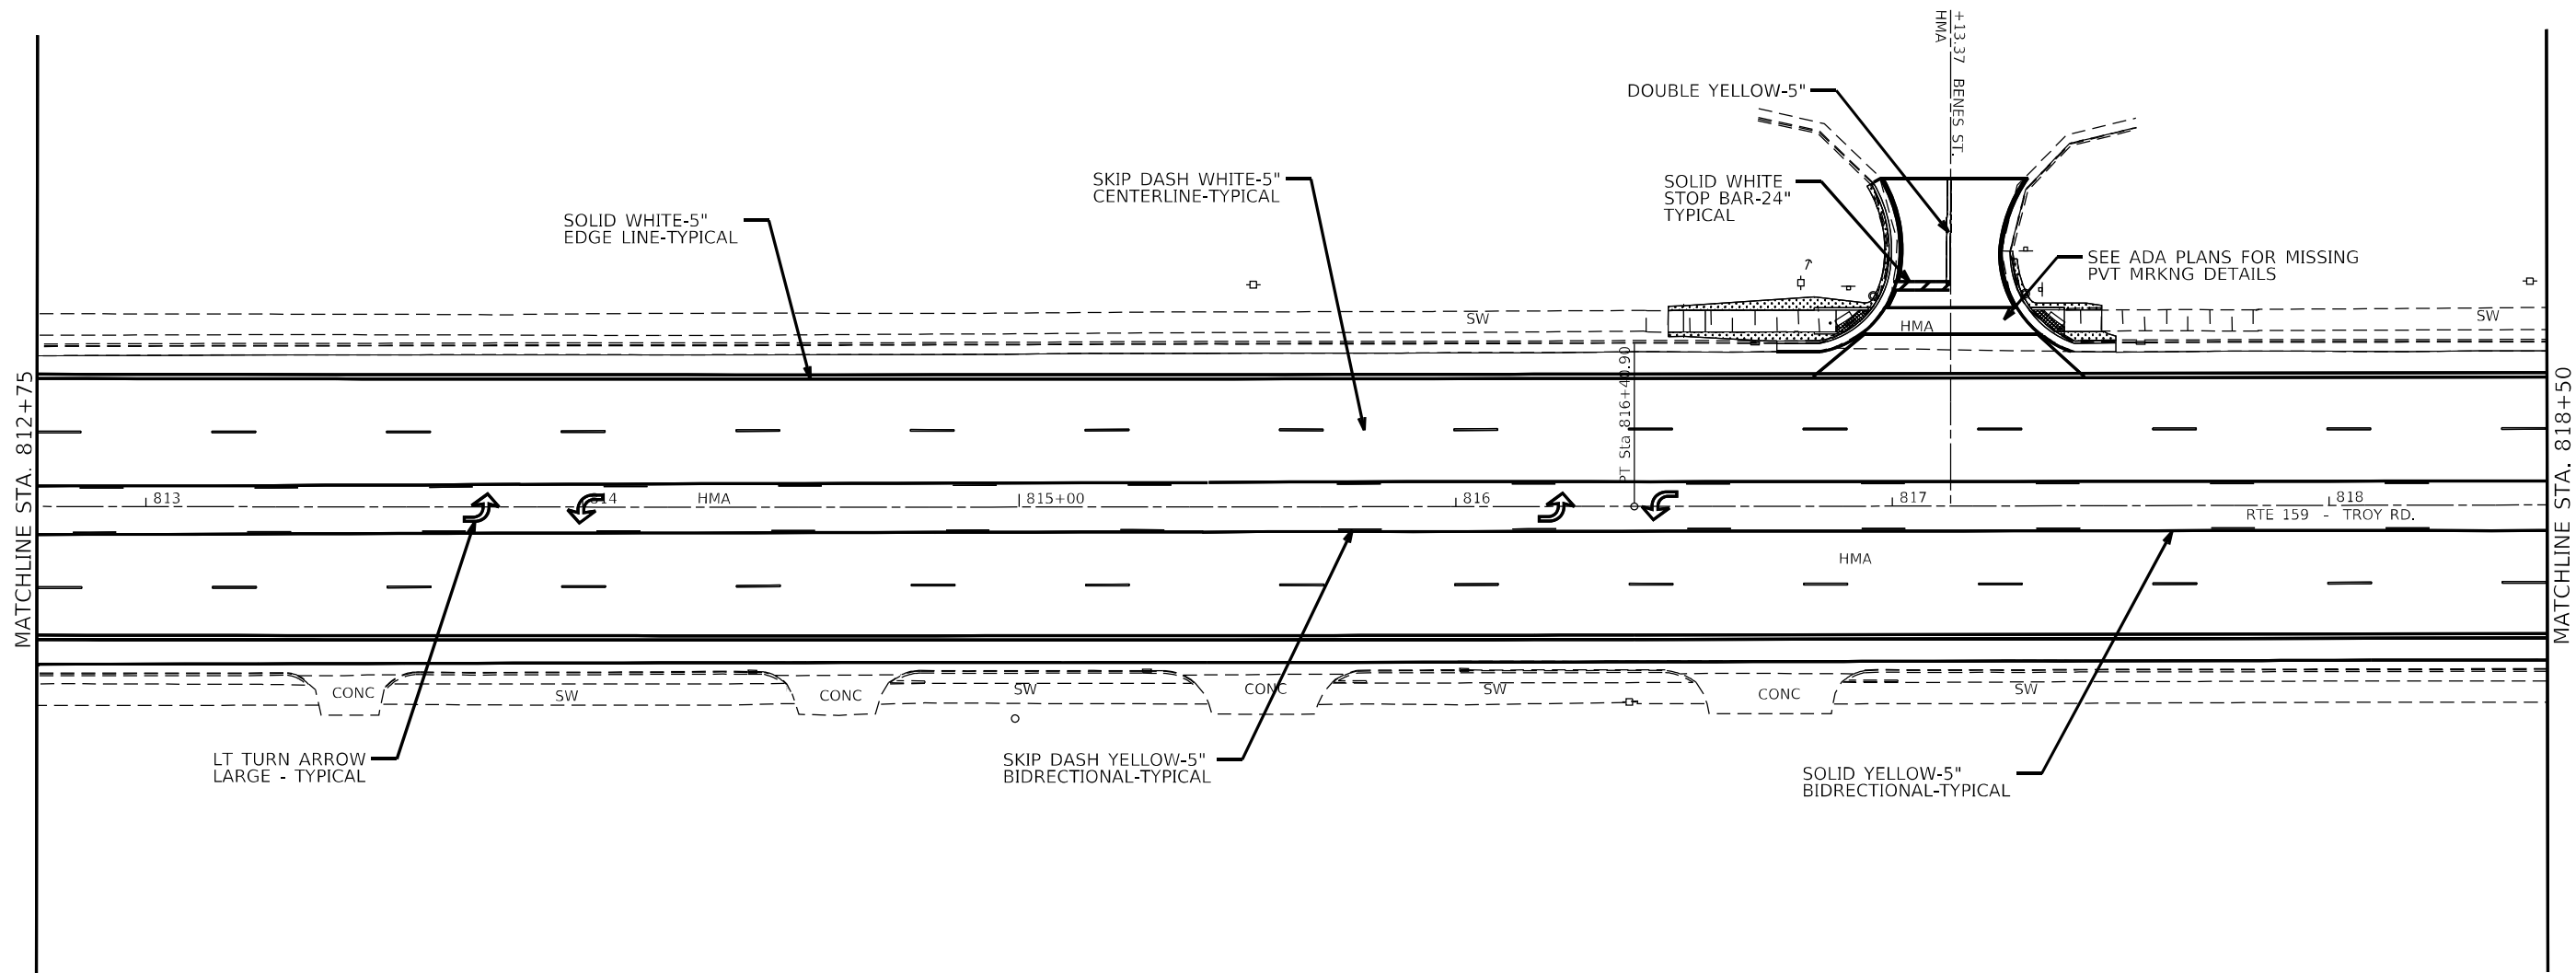


STATE OF ILLINOIS
DEPARTMENT OF TRANSPORTATION

FAP/J RTE.	SECTION	COUNTY	TOTAL SHEETS	SHEET NO.
*	(122,122-1,30)RS-4	MADISON	328	221
*600/8887		CONTRACT NO. 76M87		
	ILLINOIS	FED. AID PROJECT		

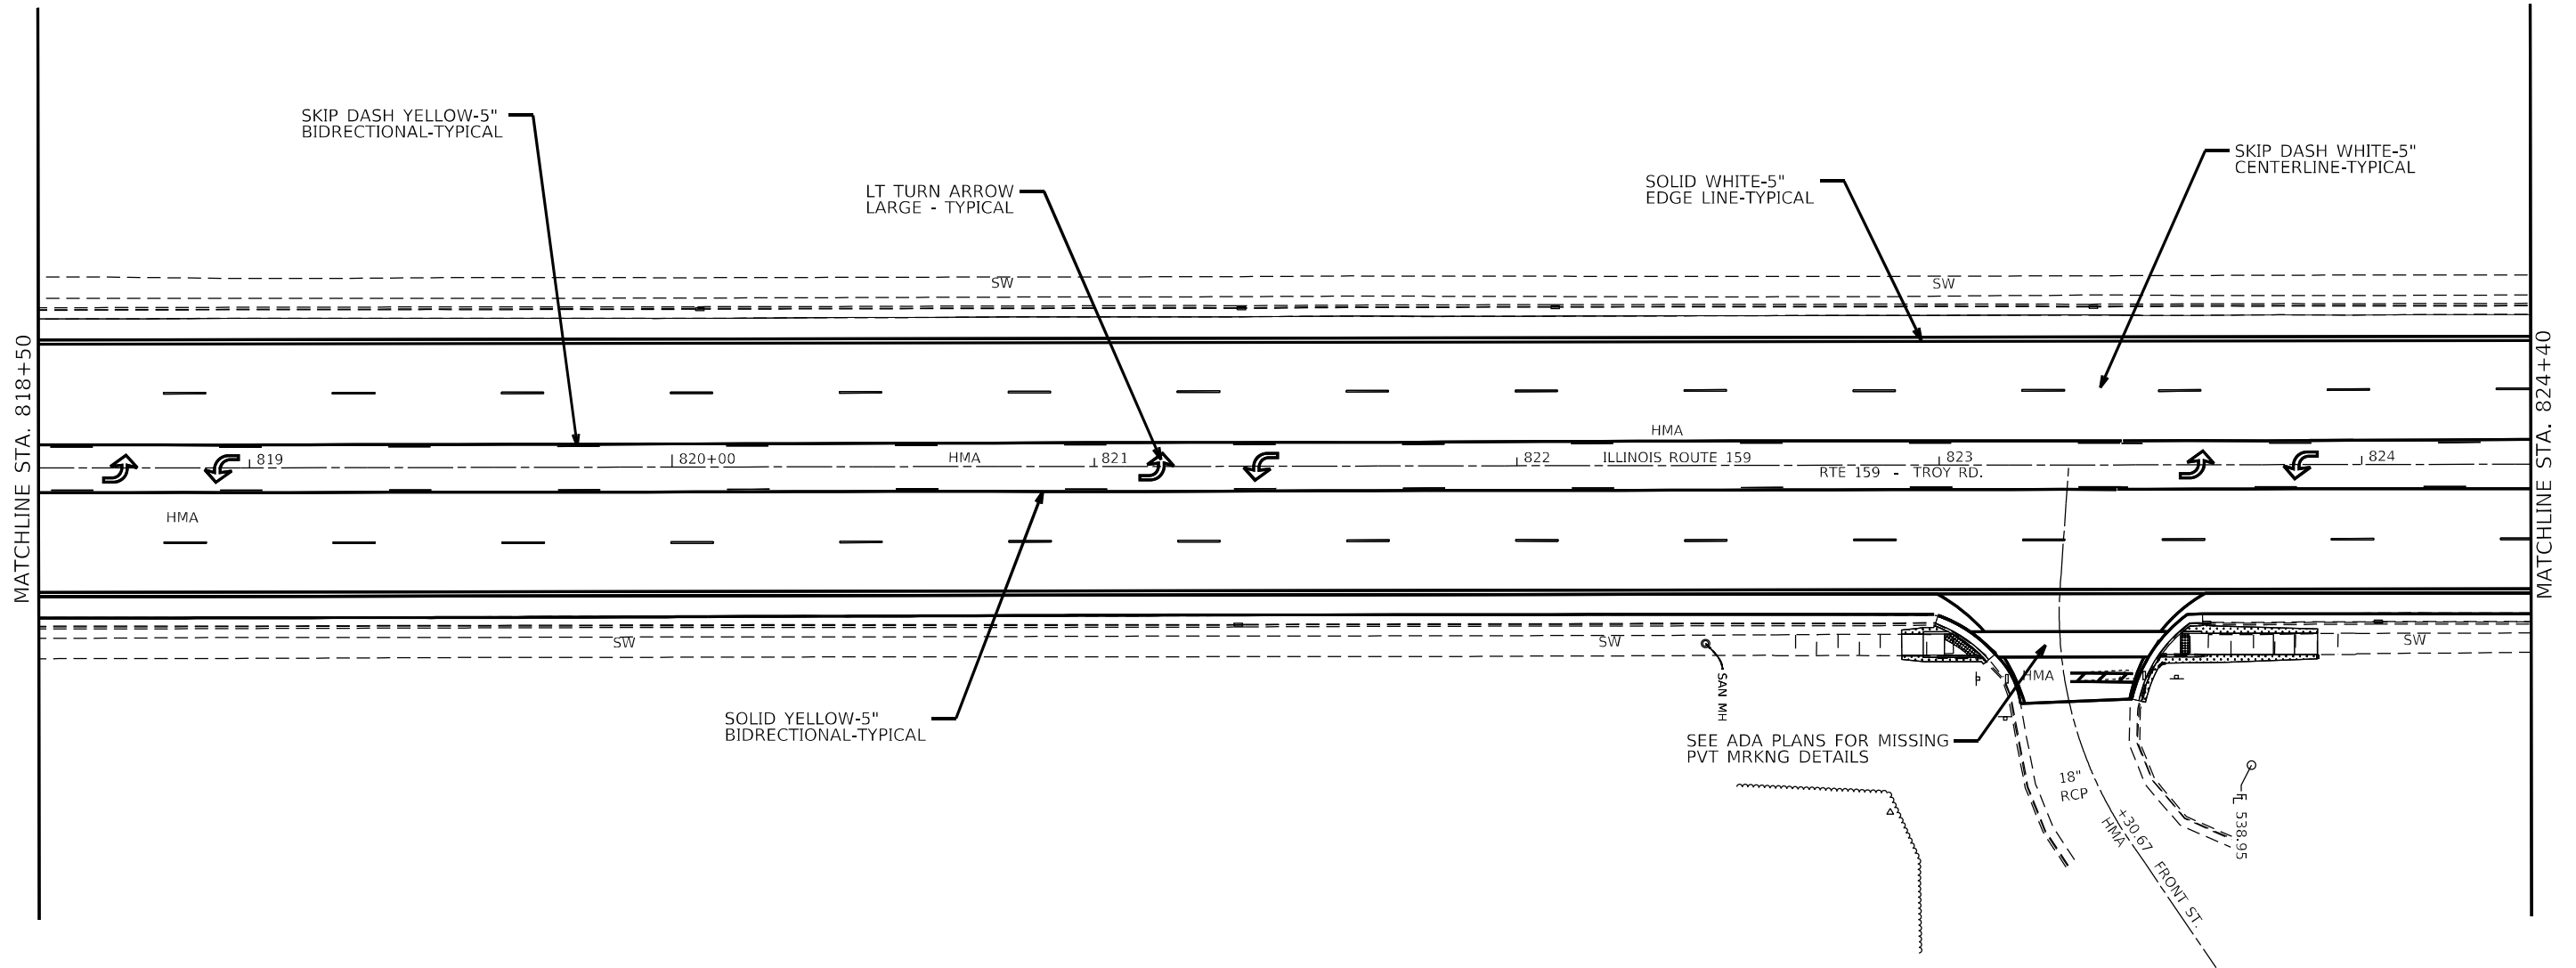


FILE NAME ID	USER NAME = edison.zoifonyl	DESIGNED -	REVISED -	STATE OF ILLINOIS DEPARTMENT OF TRANSPORTATION	PAVEMENT MARKING				FAP/JU RTE.	SECTION	COUNTY	TOTAL SHEETS	SHEET NO.
		DRAWN -	REVISED -						*	(122,122-1,30)R-4	MADISON	328	222
	PLOT SCALE = 40,458' / in.	CHECKED -	REVISED -		600/8887	CONTRACT NO. 76M87							
	PLOT DATE = 10/26/2022	DATE -	REVISED -		SCALE: 1:20	SHEET 42	OF 64 SHEETS	STA.	TO STA.				


MODEL: ANODELXAMES
FILE: \\nares-pw\illinois\pavement\Documents\DOT Office\Draw44_8\Project\DOT\Draw44\CA3\Sheet\DOT\600\76M87\241b-spl.dgn

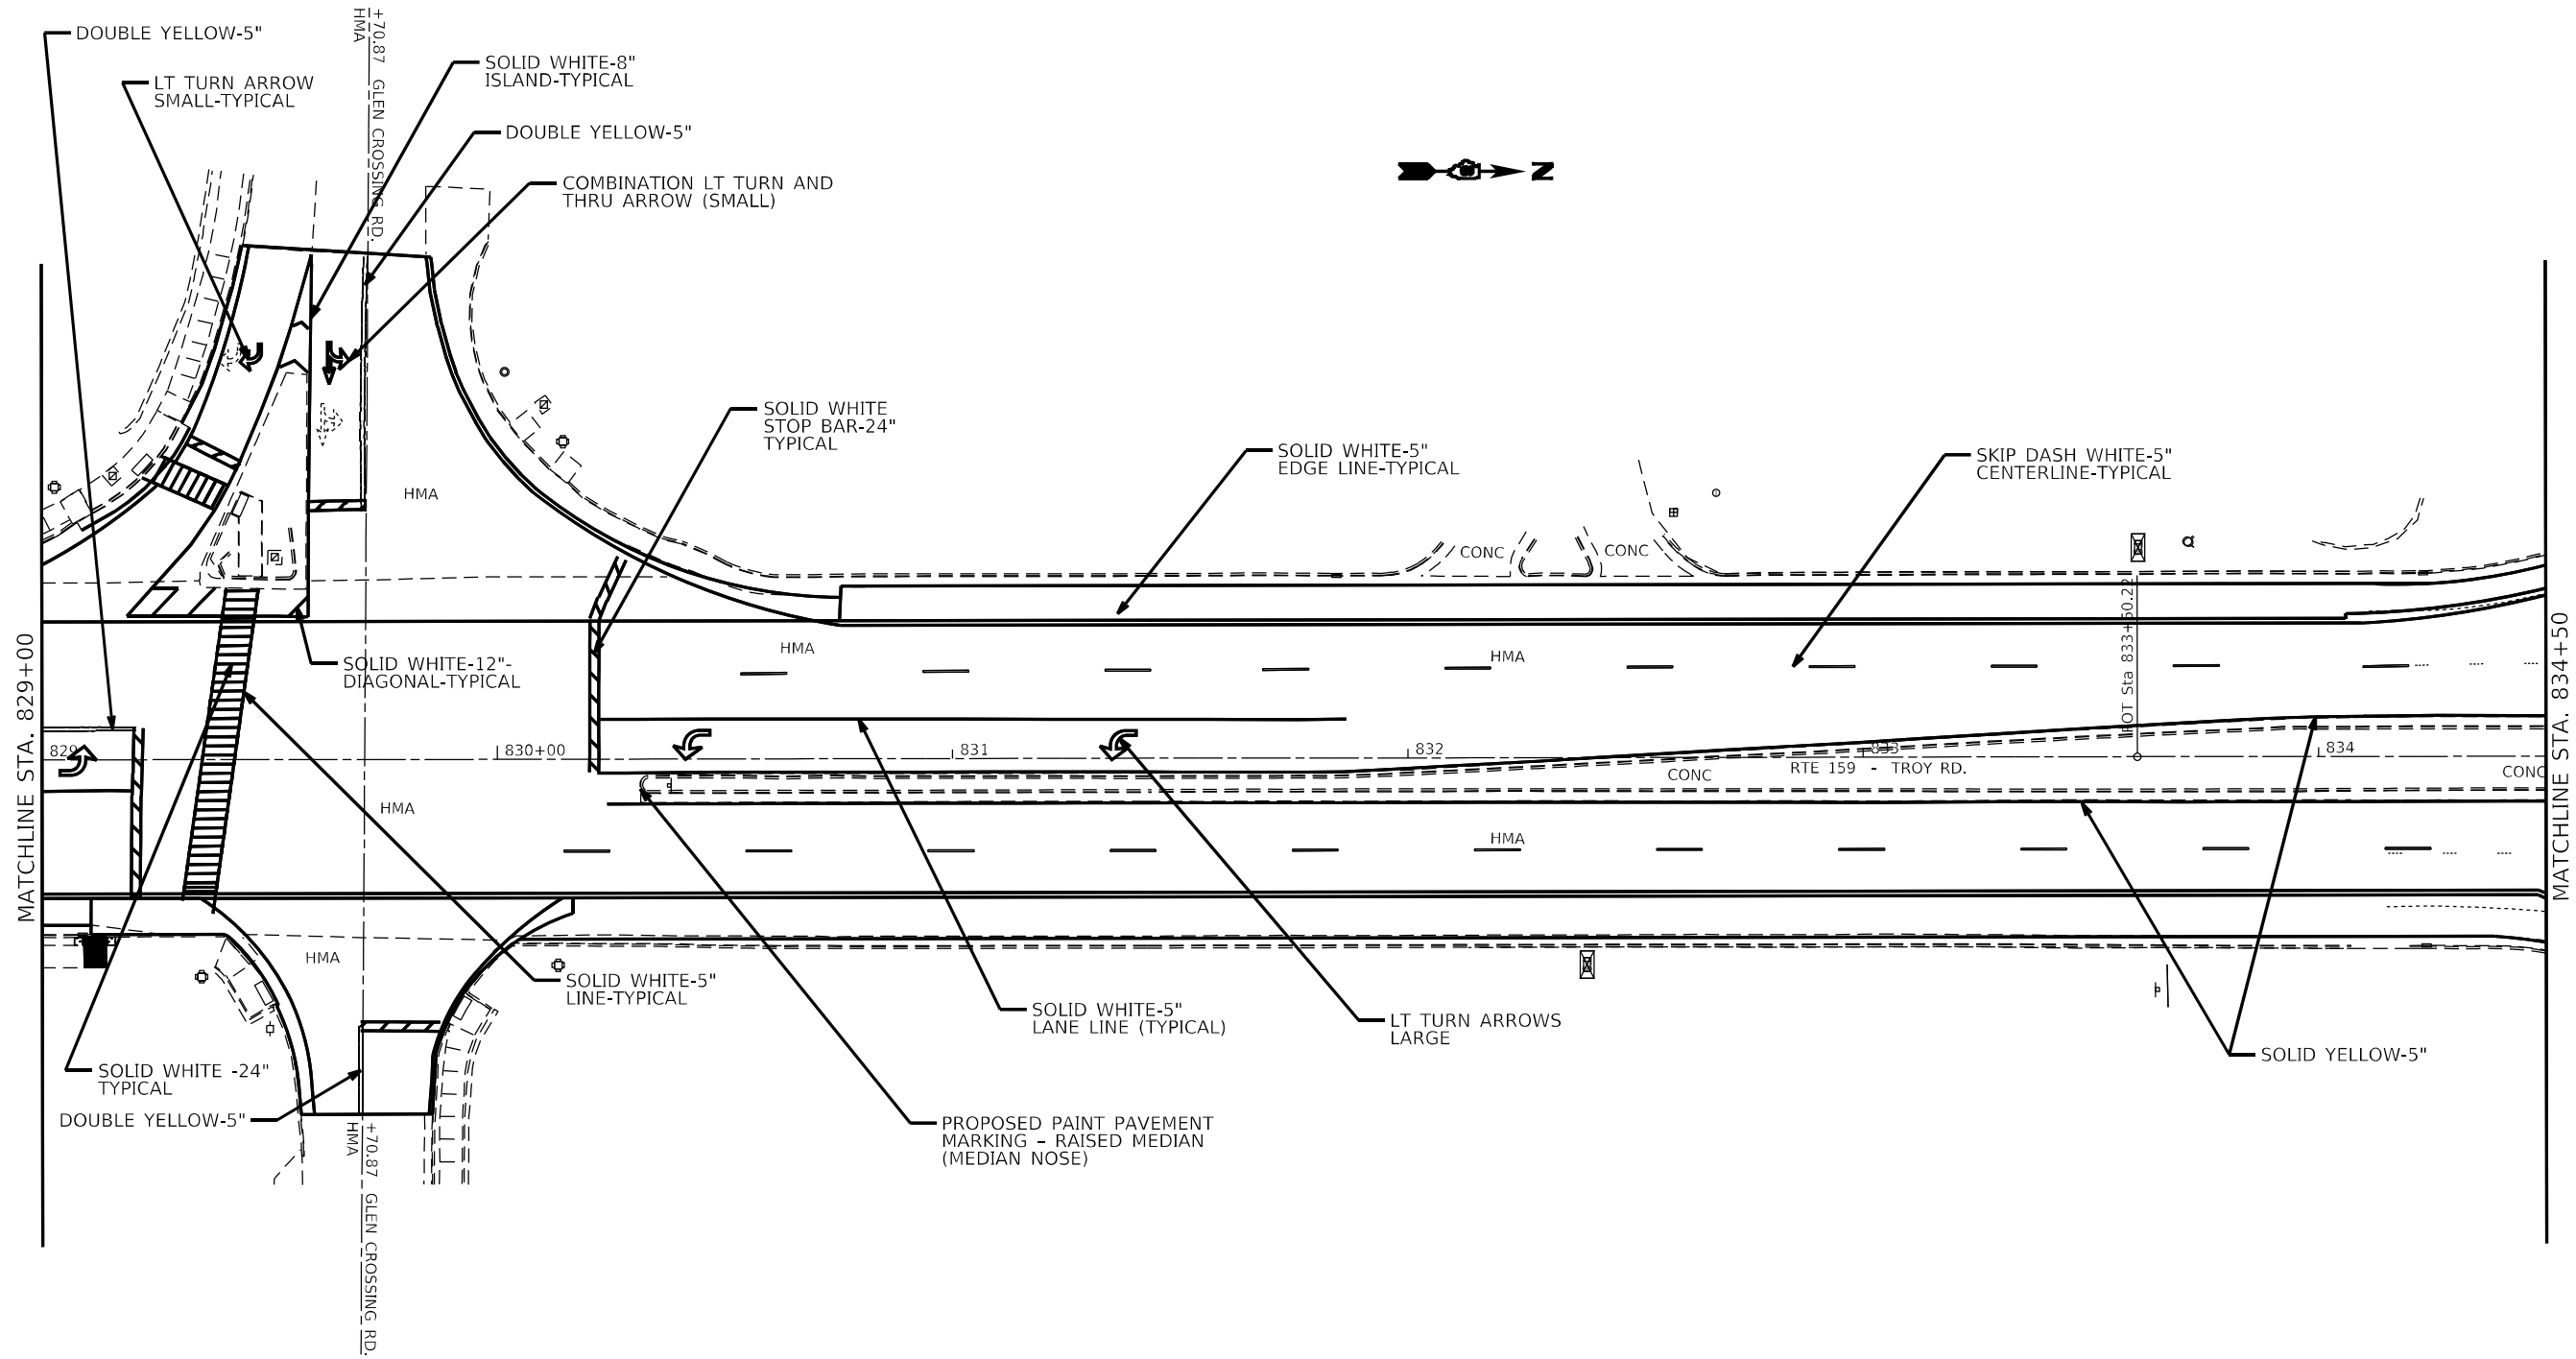

	USER NAME = edison.zo1oryi	DESIGNED -	REVISED -	STATE OF ILLINOIS DEPARTMENT OF TRANSPORTATION	PAVEMENT MARKING				FAP/U RTE.	SECTION	COUNTY	TOTAL SHEETS	SHEET NO.
		DRAWN -	REVISED -						*	(122,122-1,30)RS-4	MADISON	328	224
	PLOT SCALE = 40,4587 ' / in.	CHECKED -	REVISED -		SCALE: 1:20				SHEET 44	OF 64	SHEETS	STA.	TO STA.
	PLOT DATE = 10/26/2022	DATE -	REVISED -						CONTRACT NO. 76M87				
										ILLINOIS FED. AID PROJECT			

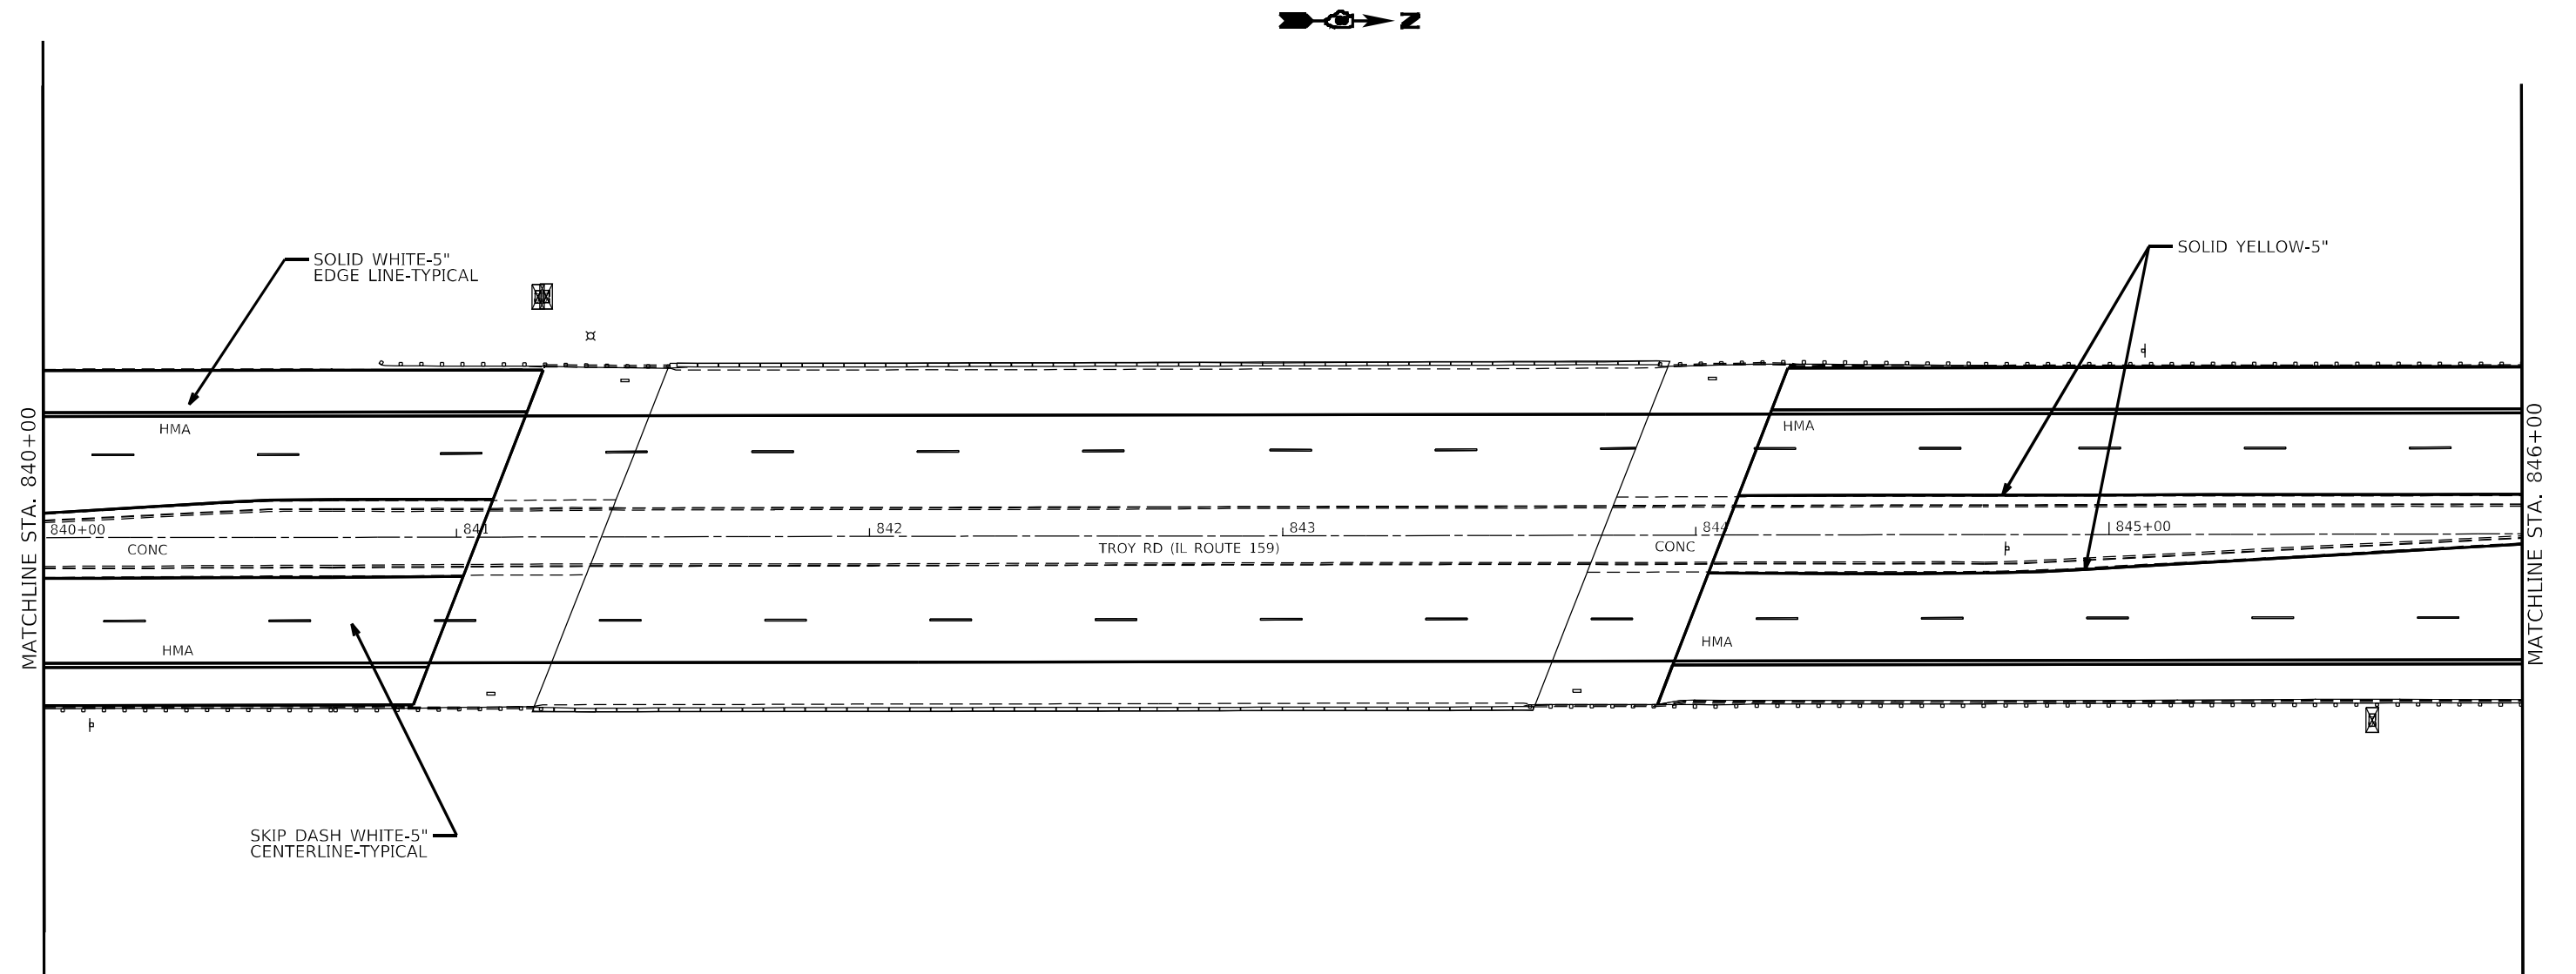

FILE NAME = D:\Pavement\PAVEMENT MARKING.dwg	USER NAME = edison.zoifonyi	DESIGNED -	REVISED -	STATE OF ILLINOIS DEPARTMENT OF TRANSPORTATION	PAVEMENT MARKING				FAD/J RTE.	SECTION	COUNTY	TOTAL SHEETS	SHEET NO.
		DRAWN -	REVISED -						*	(122.122-1.30)RS-4	MADISON	328	226
	PLOT SCALE = 40,4587' / in.	CHECKED -	REVISED -		*600/8887	CONTRACT NO. 76M87							
	PLOT DATE = 10/26/2022	DATE -	REVISED -		SCALE: 1:20	SHEET 46	OF 64 SHEETS	STA.	TO STA.	ILLINOIS	FED. AID PROJECT		

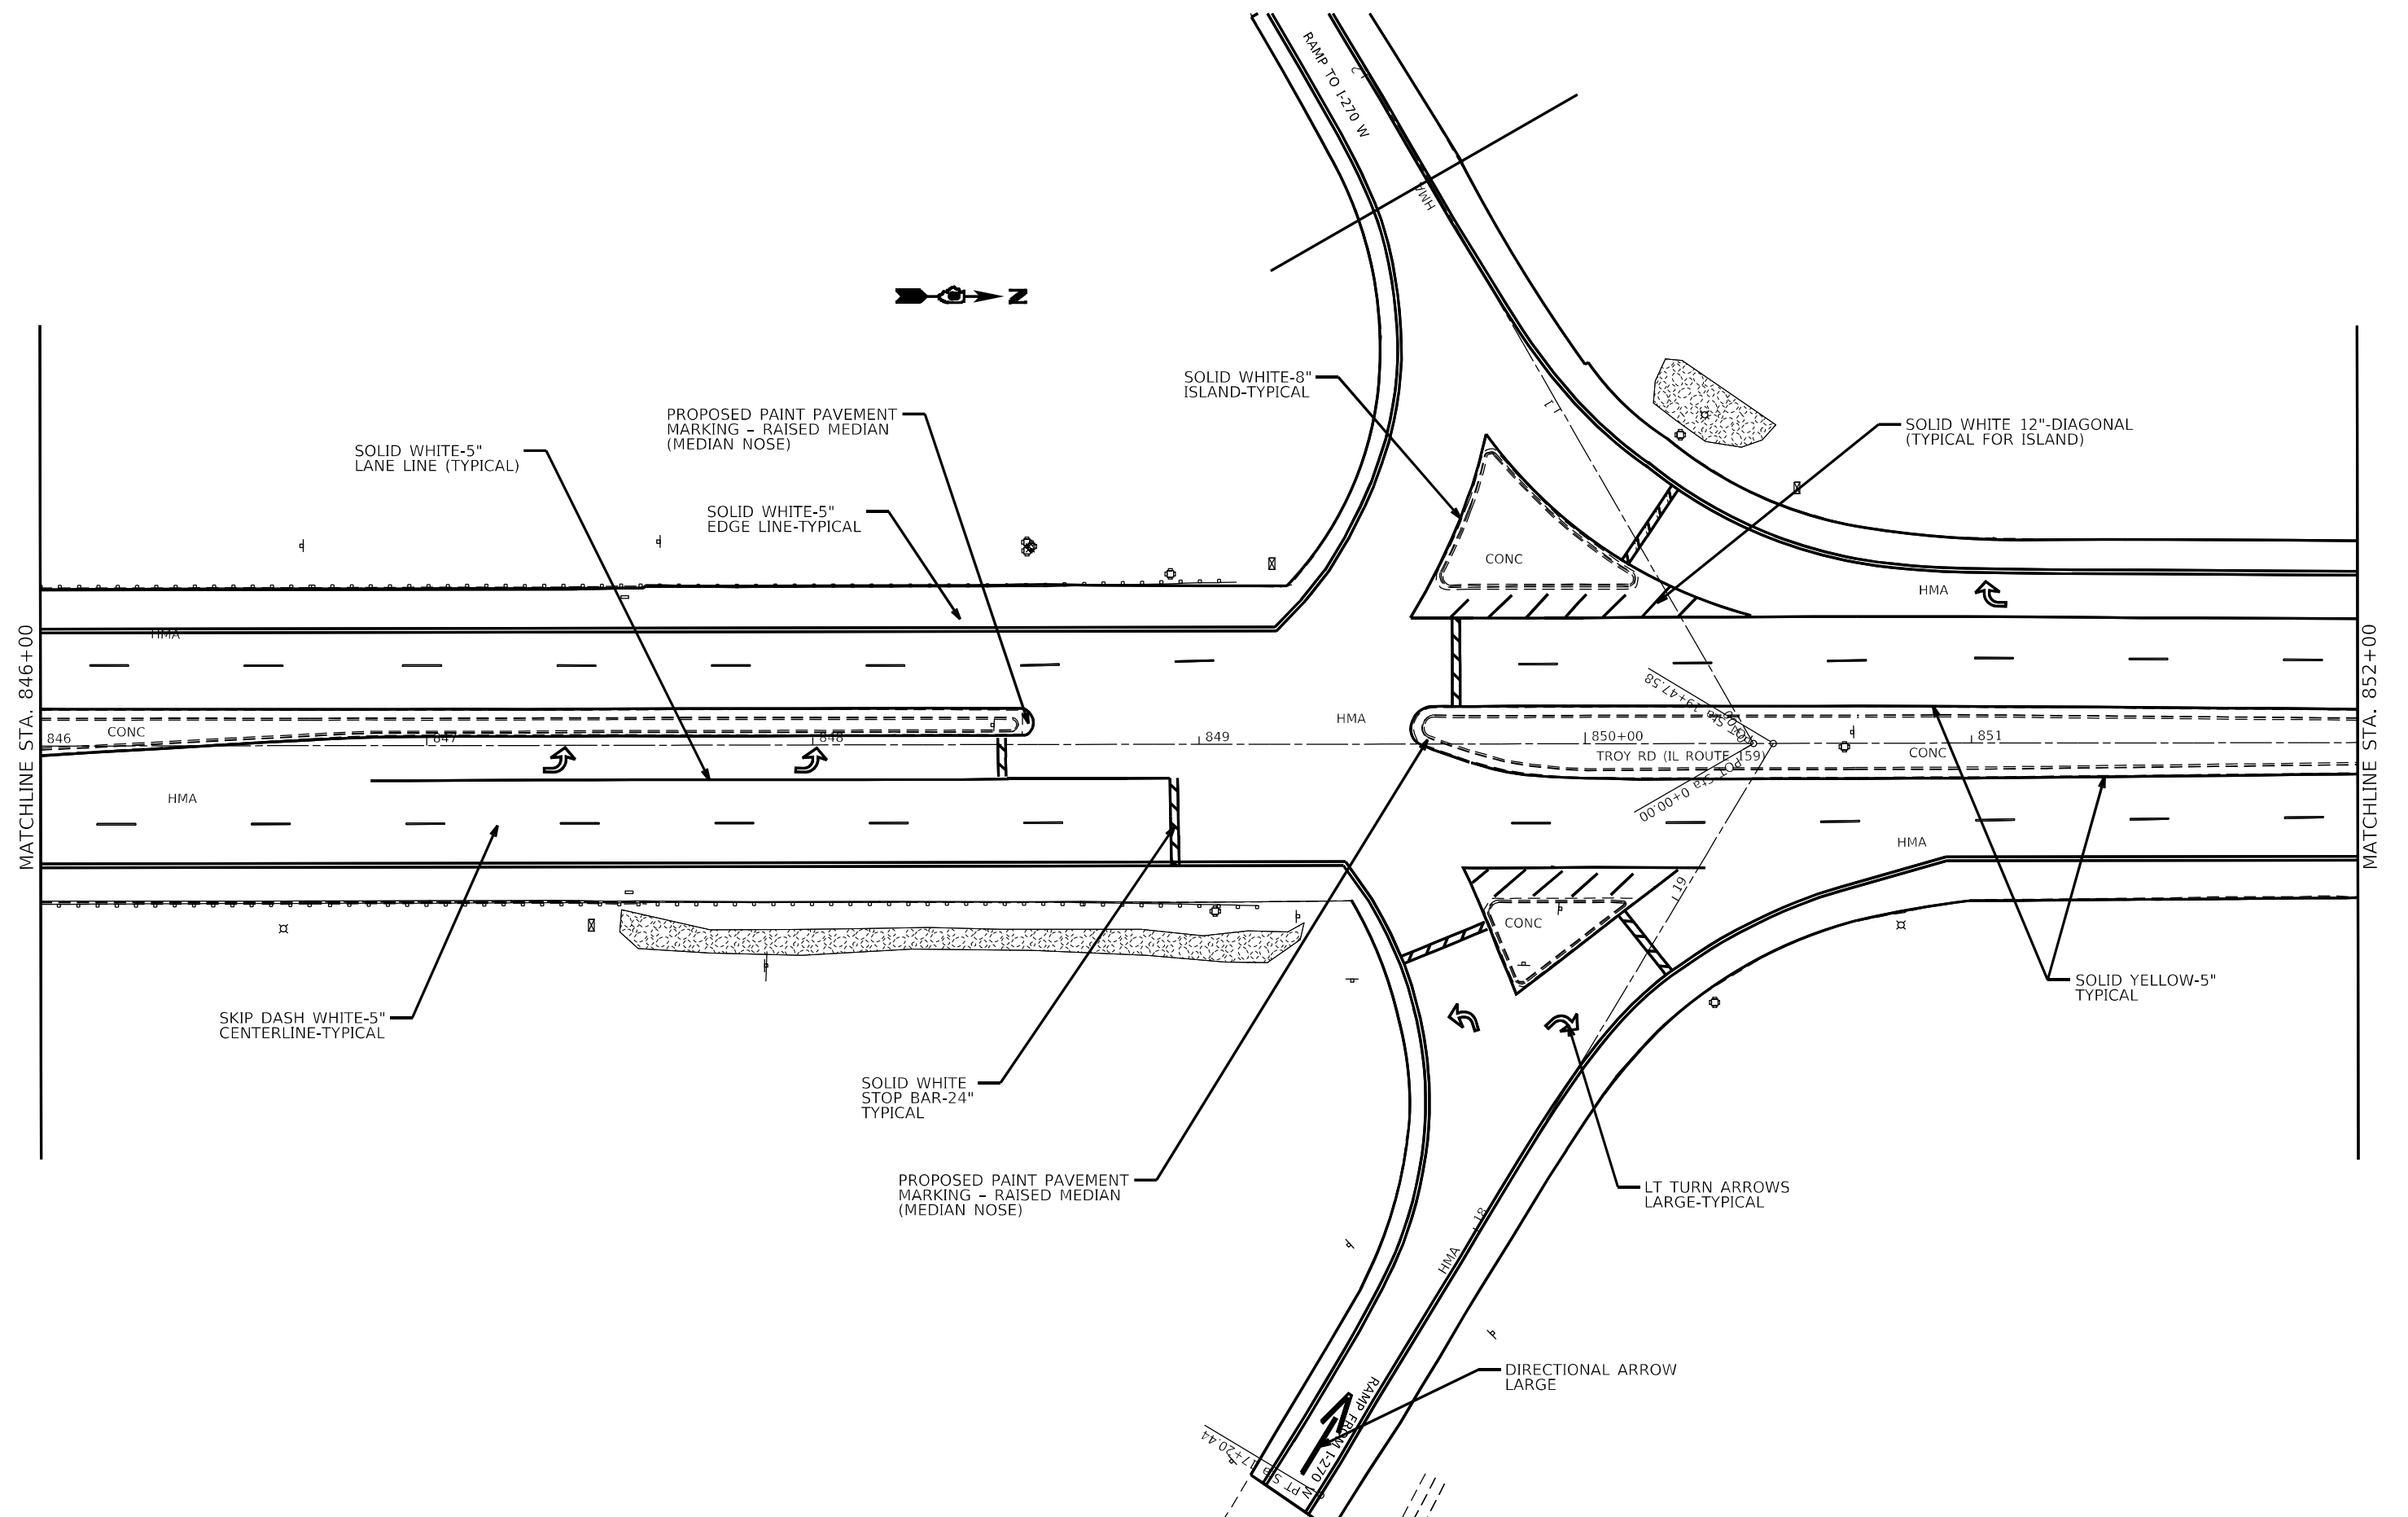

USER NAME = edison.zohforiyi	DESIGNED -	REVISED -
	DRAWN -	REVISED -
PLOT SCALE = 40,4587' / in.	CHECKED -	REVISED -
PLOT DATE = 10/26/2022	DATE -	REVISED -


**STATE OF ILLINOIS
DEPARTMENT OF TRANSPORTATION**

PAVEMENT MARKING

SCALE: 1:20	SHEET 47 OF 64 SHEETS	STA.	TO STA.
-------------	-----------------------	------	---------

FAP/U RTE.	SECTION	COUNTY	TOTAL SHEETS	SHEET NO.
*	(122,122-1,30)RS-4	MADISON	328	227
*600/8887		CONTRACT NO. 76M87		
		ILLINOIS	FED. AID	PROJECT

MODEL: ANODEL.ANAMES
FILE: \\nares-pw01\cso-bentley.com\pwwid01\Documents\DOT_Office\DrawH4_8\Project\ADB\FM67CADD\DrawH4\33\DrawH4\FM67\sub-pmk.dgn

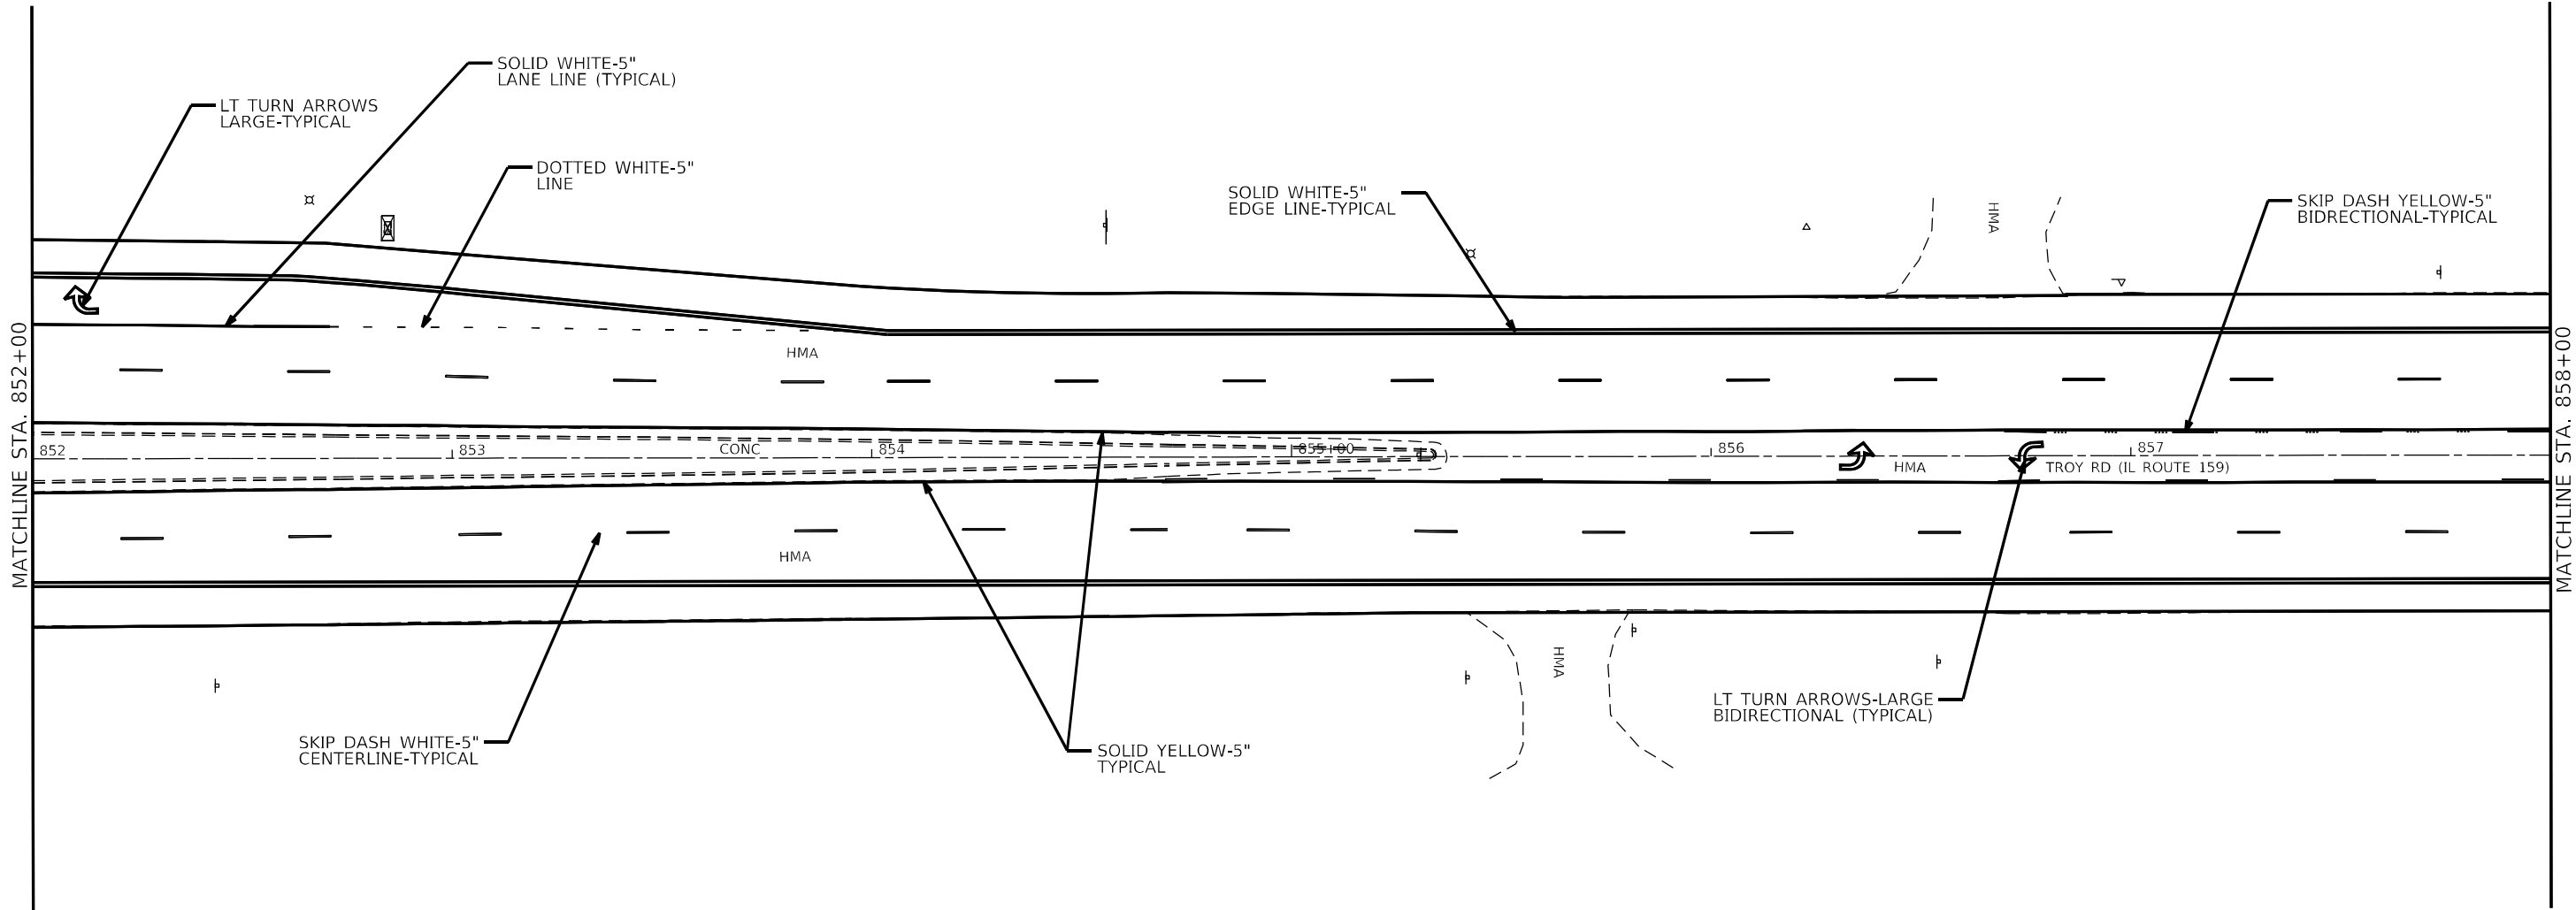

	USER NAME	= edison.zohforyi	DESIGNED	-	REVISED	-
			DRAWN	-	REVISED	-
	PLOT SCALE	= 40.4587' / in.	CHECKED	-	REVISED	-
	PLOT DATE	= 10/26/2022	DATE	-	REVISED	-


STATE OF ILLINOIS
DEPARTMENT OF TRANSPORTATION

PAVEMENT MARKING


SCALE: 1:20 SHEET 48 OF 64 SHEETS STA. TO STA.

FAP/U RTE.	SECTION	COUNTY	TOTAL SHEETS	SHEET NO.
*	(122,122-1,30)/RS-4	MADISON	328	228
*600/8887		CONTRACT NO. 76M87		
		ILLINOIS	FED. AID PROJECT	

MODEL: ANODELAMIES
FILE: \\nares-pw\illinois\paw\benley.com\BMDOT\Documents\BMDOT_Offices\BMDOT_8\Project\BDB\FMGT\CADD\BDB\FMGT\BDB\FMGT\2410-001.dgn

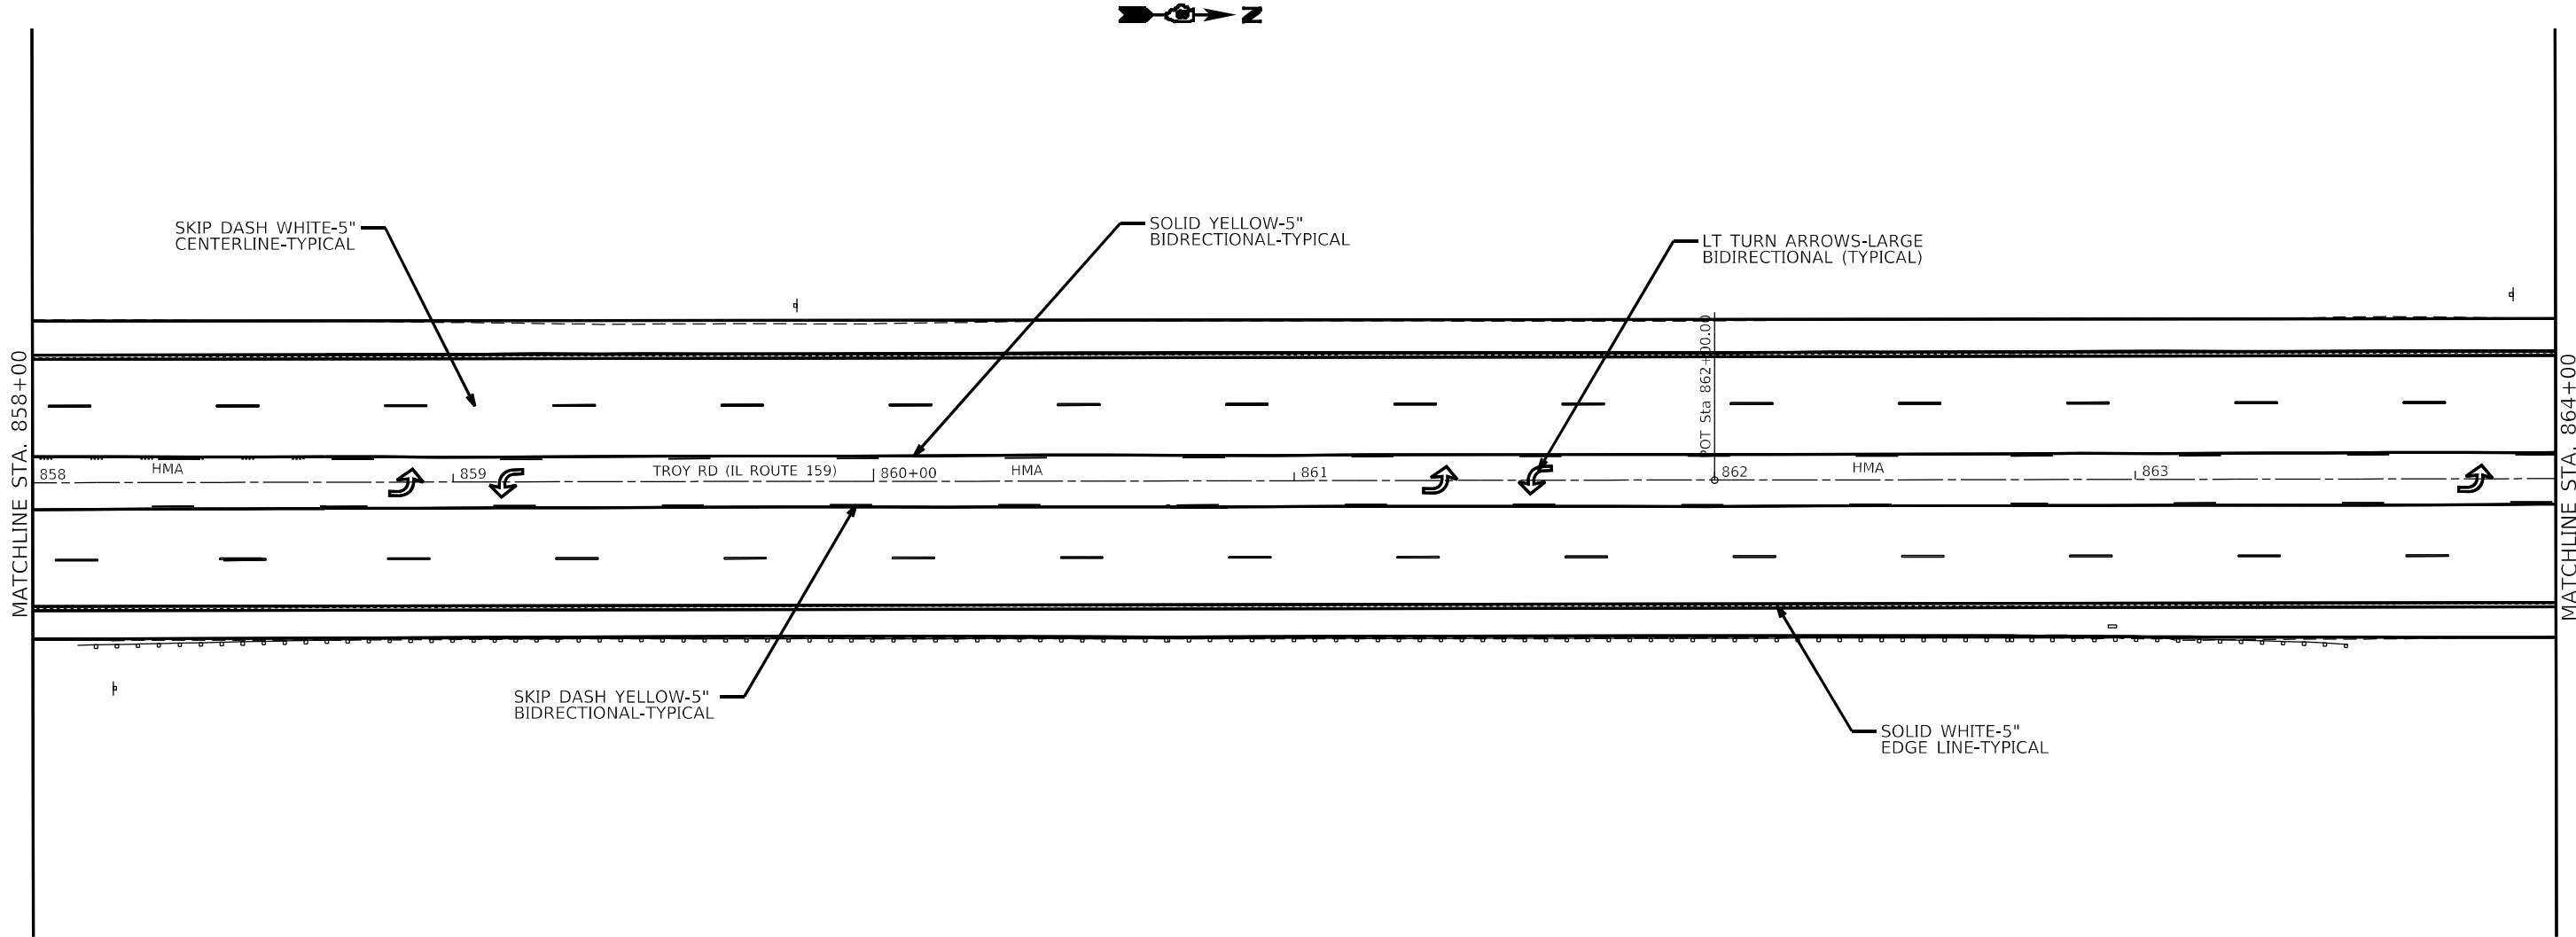

	USER NAME	= edison.zonforyi	DESIGNED	-	REVISED	-	STATE OF ILLINOIS DEPARTMENT OF TRANSPORTATION	PAVEMENT MARKING				FAP/U RTE.	SECTION	COUNTY	TOTAL SHEETS	SHEET NO.	
			DRAWN	-	REVISED	-						*	(122,122-1,30)RS-4	MADISON	328	229	
	PLOT SCALE	= 40,4587 ' / in.	CHECKED	-	REVISED	-						*600/8887		CONTRACT NO. 76M87			
	PLOT DATE	= 10/26/2022	DATE	-	REVISED	-						SCALE: 1:20		SHEET 49	OF 64	SHEETS	STA.

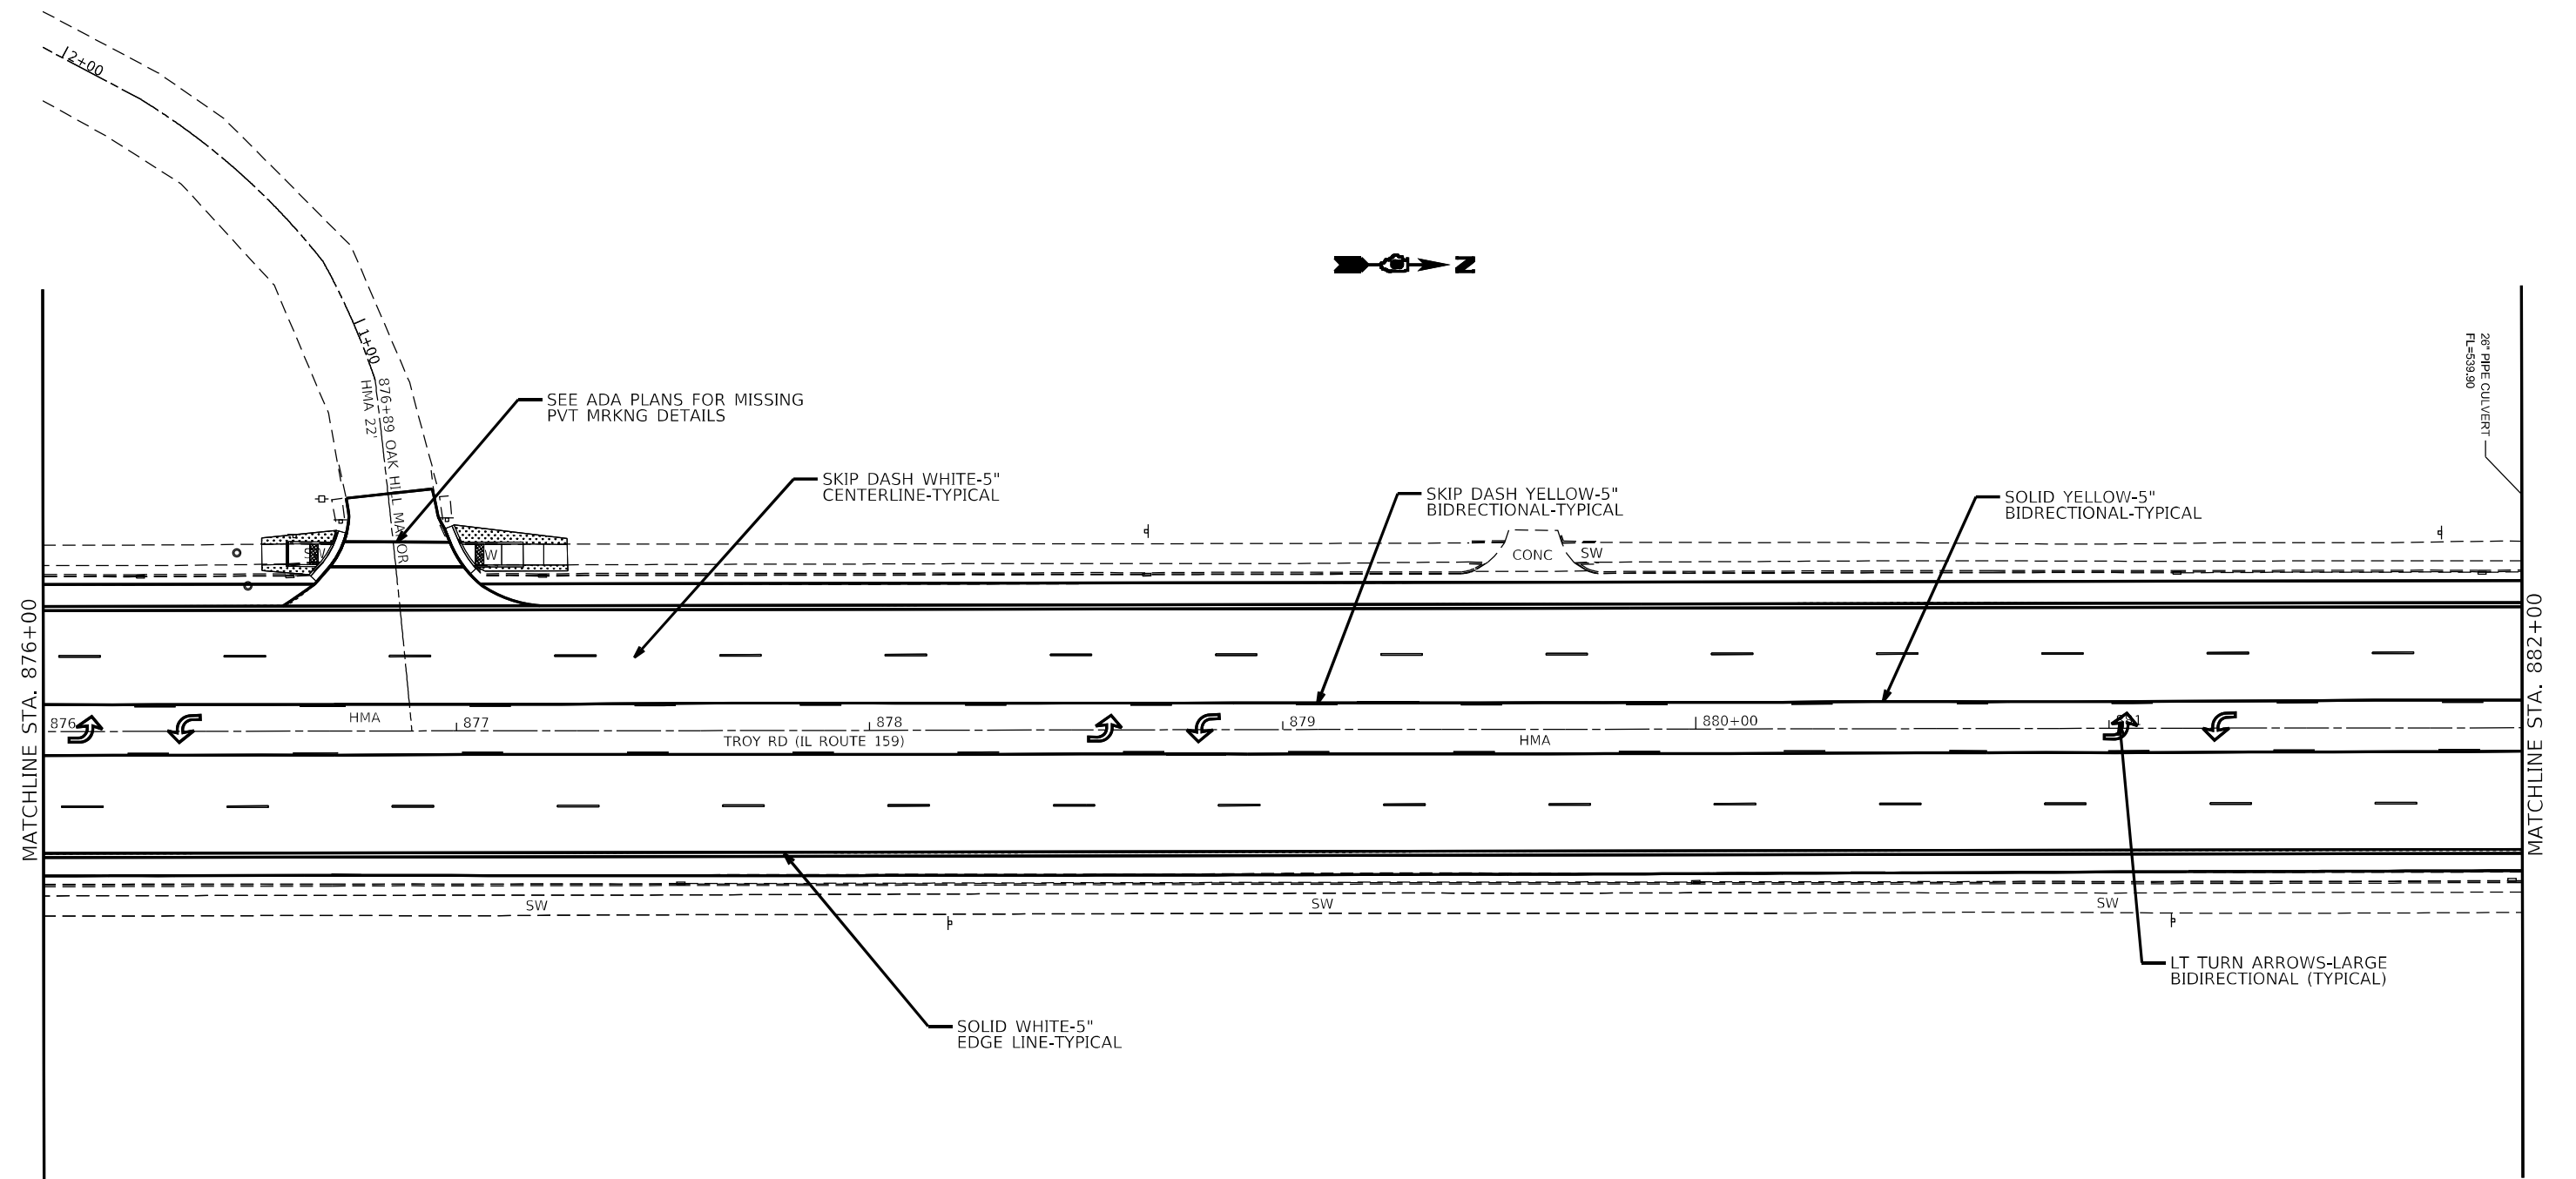


USER NAME = edison.zohforyi	DESIGNED -	REVISED -	STATE OF ILLINOIS DEPARTMENT OF TRANSPORTATION	PAVEMENT MARKING			FAP/U RTE.	SECTION	COUNTY	TOTAL SHEETS	SHEET NO.
	DRAWN -	REVISED -					*	(122,122-1,30)RS-4	MADISON	328	232
PLOT SCALE = 40,4587' / in.	CHECKED -	REVISED -		SCALE: 1:20			SHEET 52 OF 64 SHEETS	STA. TO STA.		*600/8887	
PLOT DATE = 10/26/2022	DATE -	REVISED -							ILLINOIS		FED. AID PROJECT
									CONTRACT NO. 76M87		



MODEL: \$MODELNAME\$
FILE NAME: pw:\Vldot-pw\

MODEL: ANODEL.ANAMES
FILE: \\nares-pw\illinois\paw_bentley.com\DWG\DOT\Documents\DOT - Office\Drawn\4. 8\Project\DWG\6M\7CADD\alca\3\sheet\DWG\6M\7C\h-ent\1.dgn

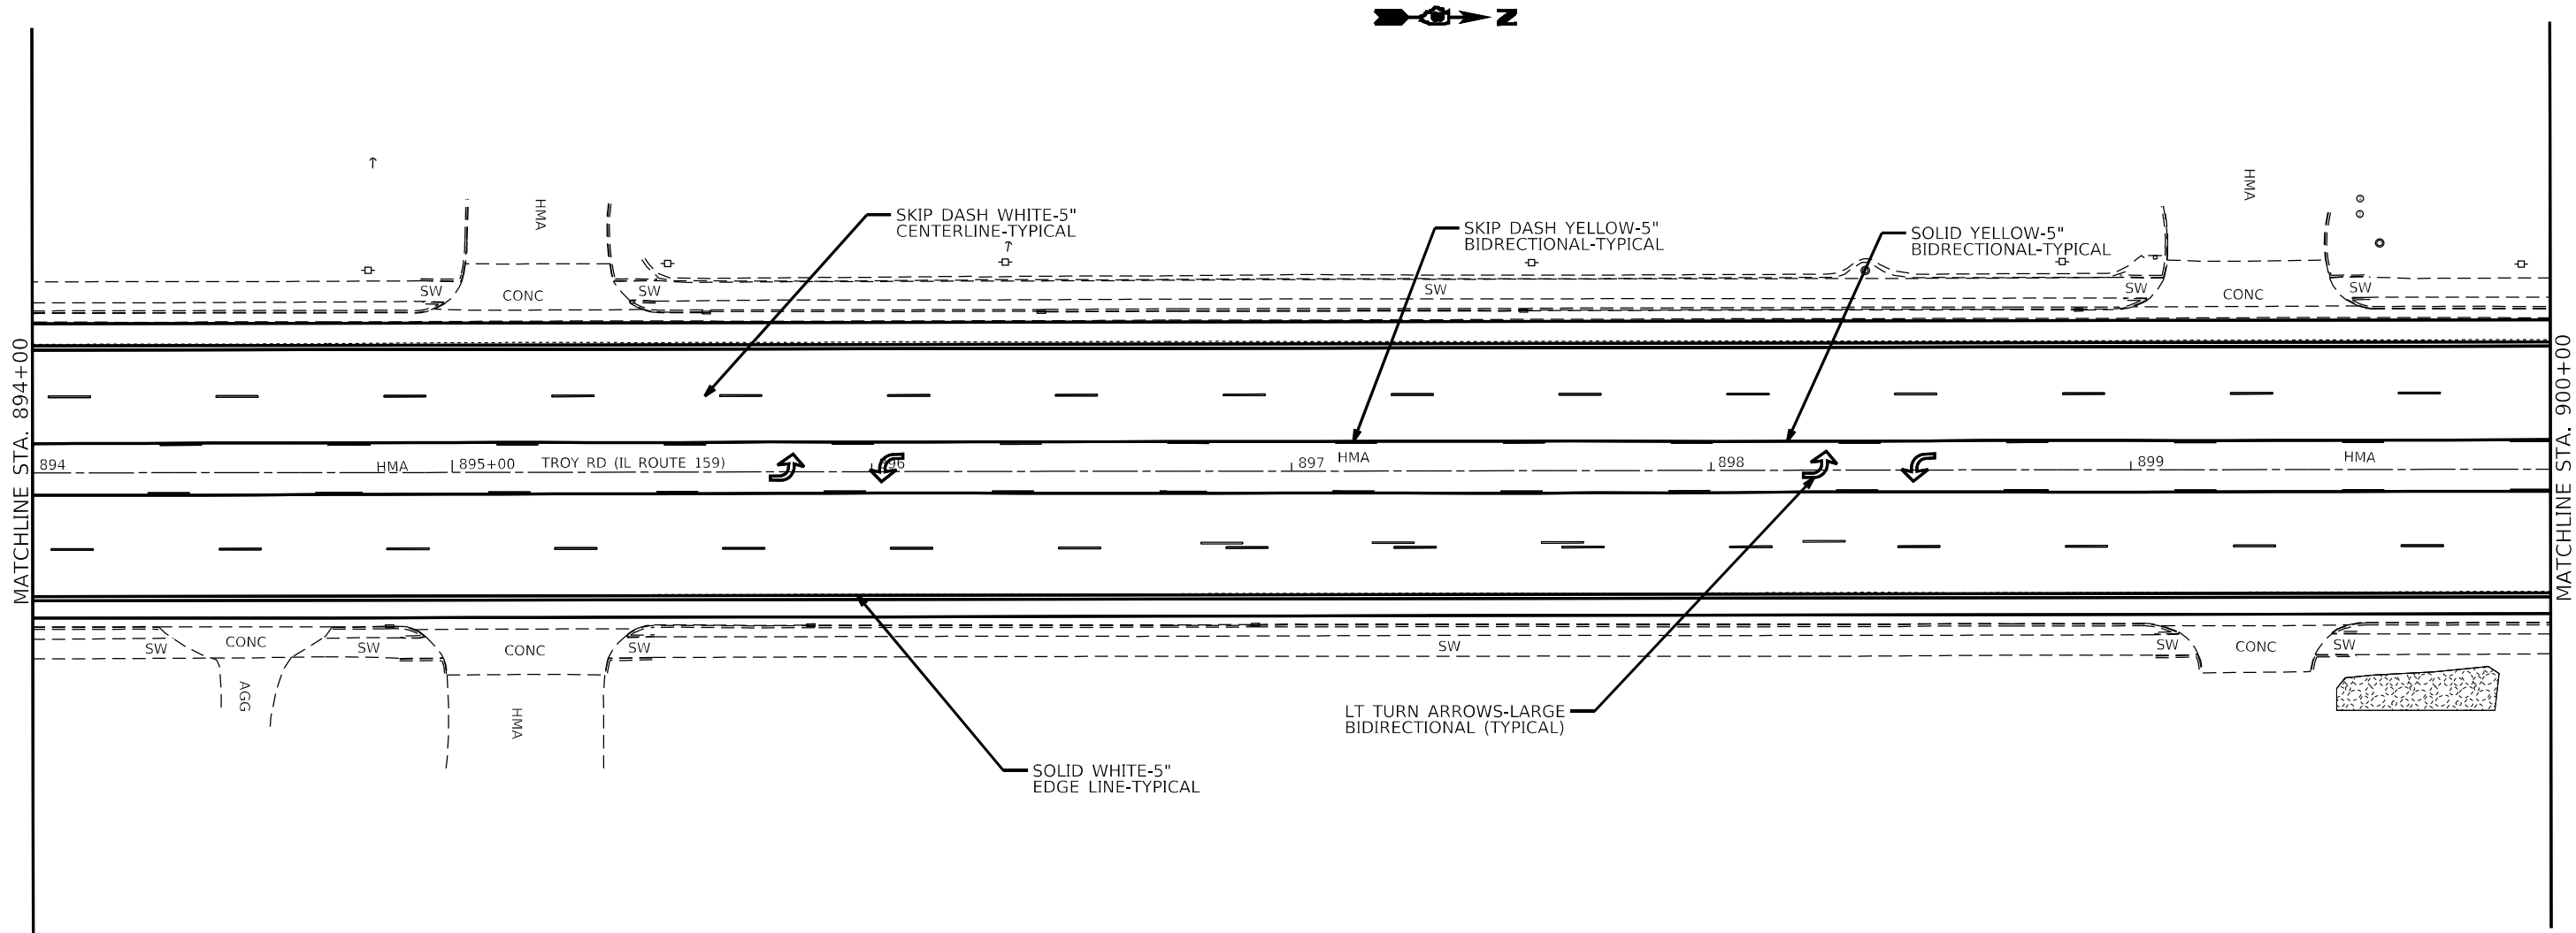


	USER NAME	= edison.zohforyi	DESIGNED	-	REVISED	-
			DRAWN	-	REVISED	-
	PLOT SCALE	= 40,4587 ' / in.	CHECKED	-	REVISED	-
	PLOT DATE	= 10/26/2022	DATE	-	REVISED	-

STATE OF ILLINOIS
DEPARTMENT OF TRANSPORTATION

PAVEMENT MARKING

SCALE: 1:20 SHEET 55 OF 64 SHEETS STA. TO STA.


FAP/U RTE.	SECTION	COUNTY	TOTAL SHEETS	SHEET NO.
*	(122,122-1,30)RS-4	MADISON	328	235
*600/8887		CONTRACT NO. 76M87		
ILLINOIS		FED. AID PROJECT		

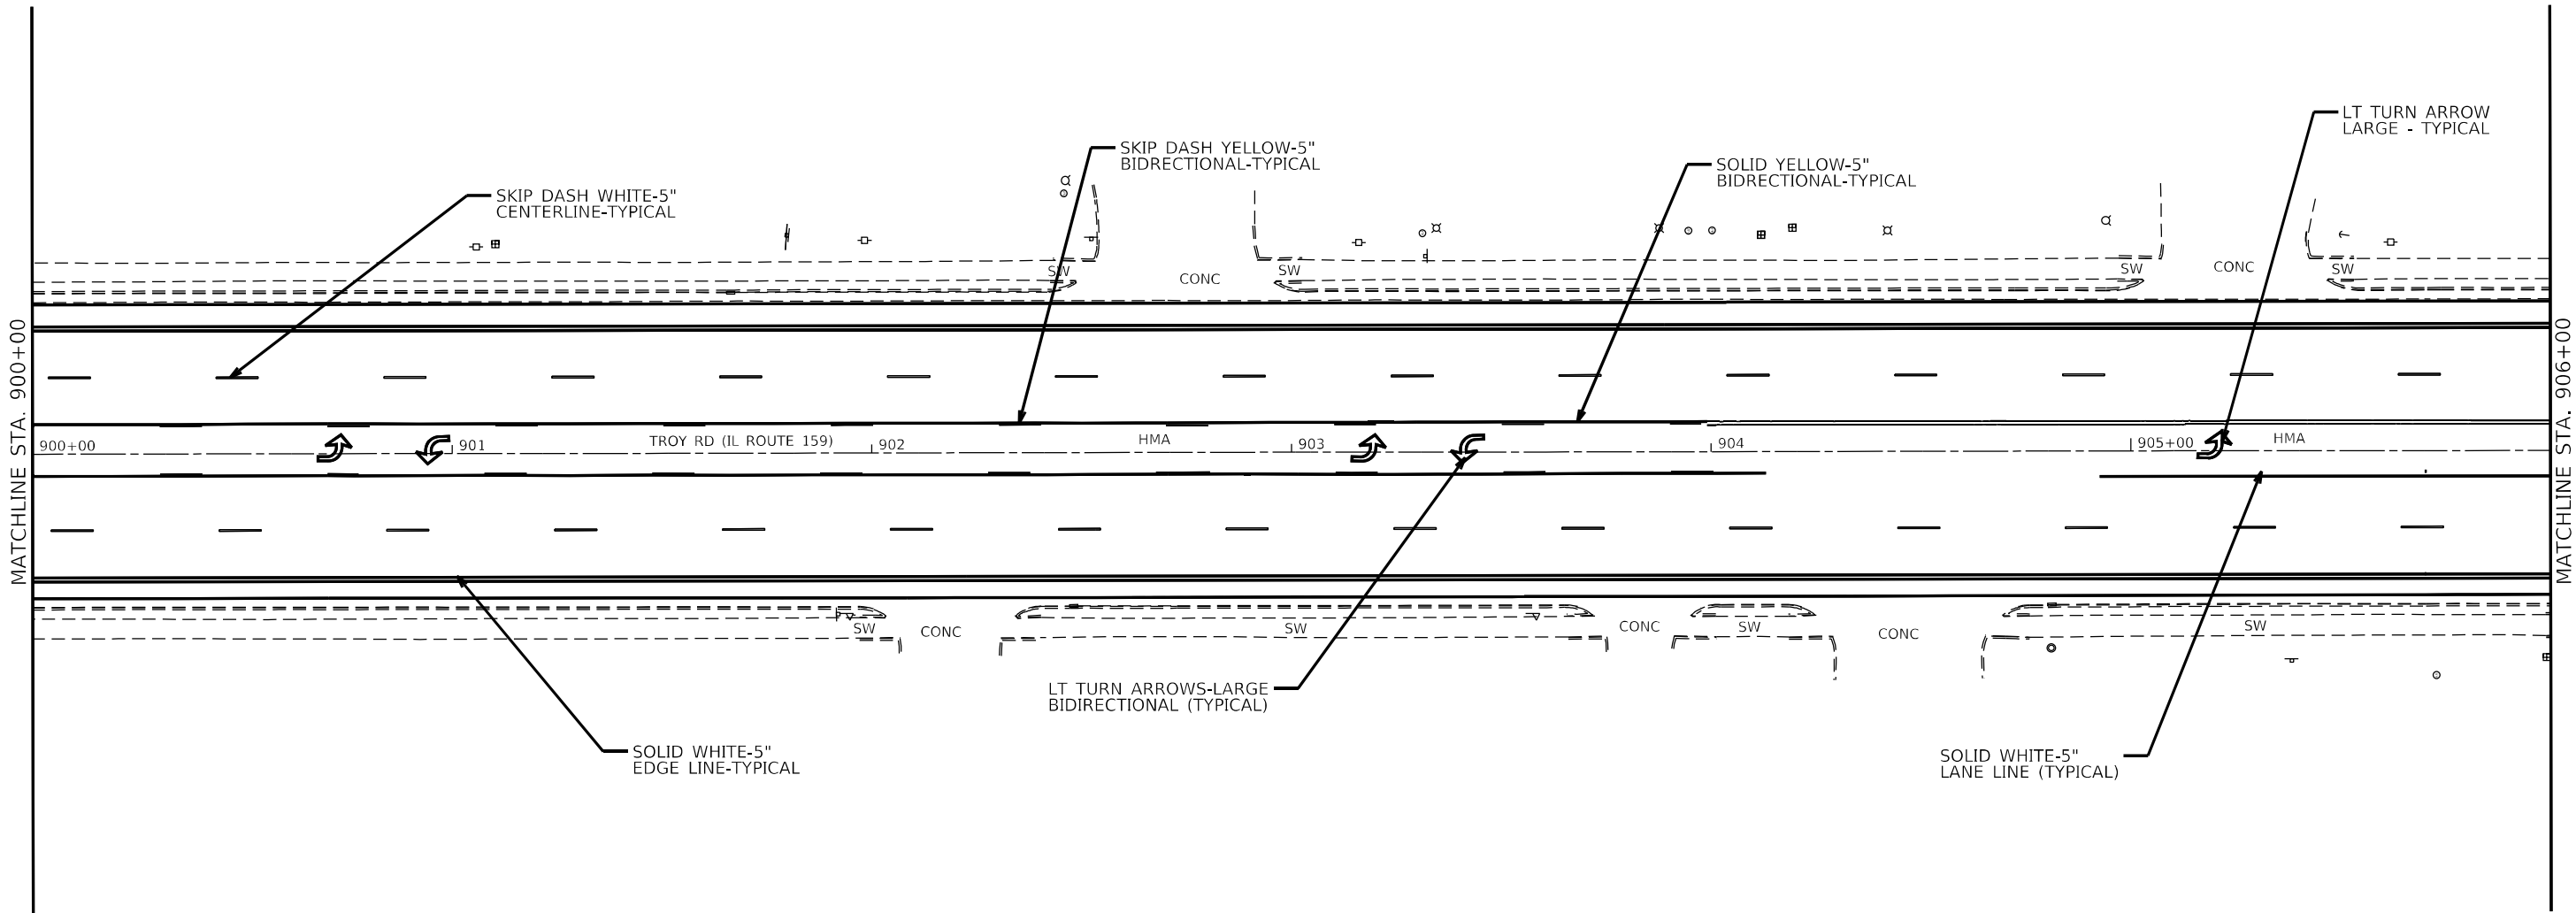

MODEL: ANODELX.MXS
FILE: \\nares-pc\illinois\pavement\concrete\WIDOT\Documents\JUDOT_Office\JUDot14_8\Project\JUDOT\BMD\TCD\Data\CA3\Sheet5\JUDOT\BMD\74511-001.dgn


	USER NAME	= edison.zonforyi	DESIGNED	-	REVISED	-	STATE OF ILLINOIS DEPARTMENT OF TRANSPORTATION	PAVEMENT MARKING				FAP/U RTE.	SECTION	COUNTY	TOTAL SHEETS	SHEET NO.	
			DRAWN	-	REVISED	-						*	(122,122-1,30)RS-4	MADISON	328	236	
	PLOT SCALE	= 40,4587' / in.	CHECKED	-	REVISED	-						*600/8887		CONTRACT NO. 76M87			
	PLOT DATE	= 10/26/2022	DATE	-	REVISED	-						SCALE: 1:20		SHEET 56	OF 64	SHEETS	STA.

MODEL: ANODELX.MXS
FILE: \\MSRVS-PA01\usps\hantley.com\DWG\DOT\Documents\DOT - Office\Drawn\4. 8\Project\122-1.30\RS-4\BMD\7411-001.dwg

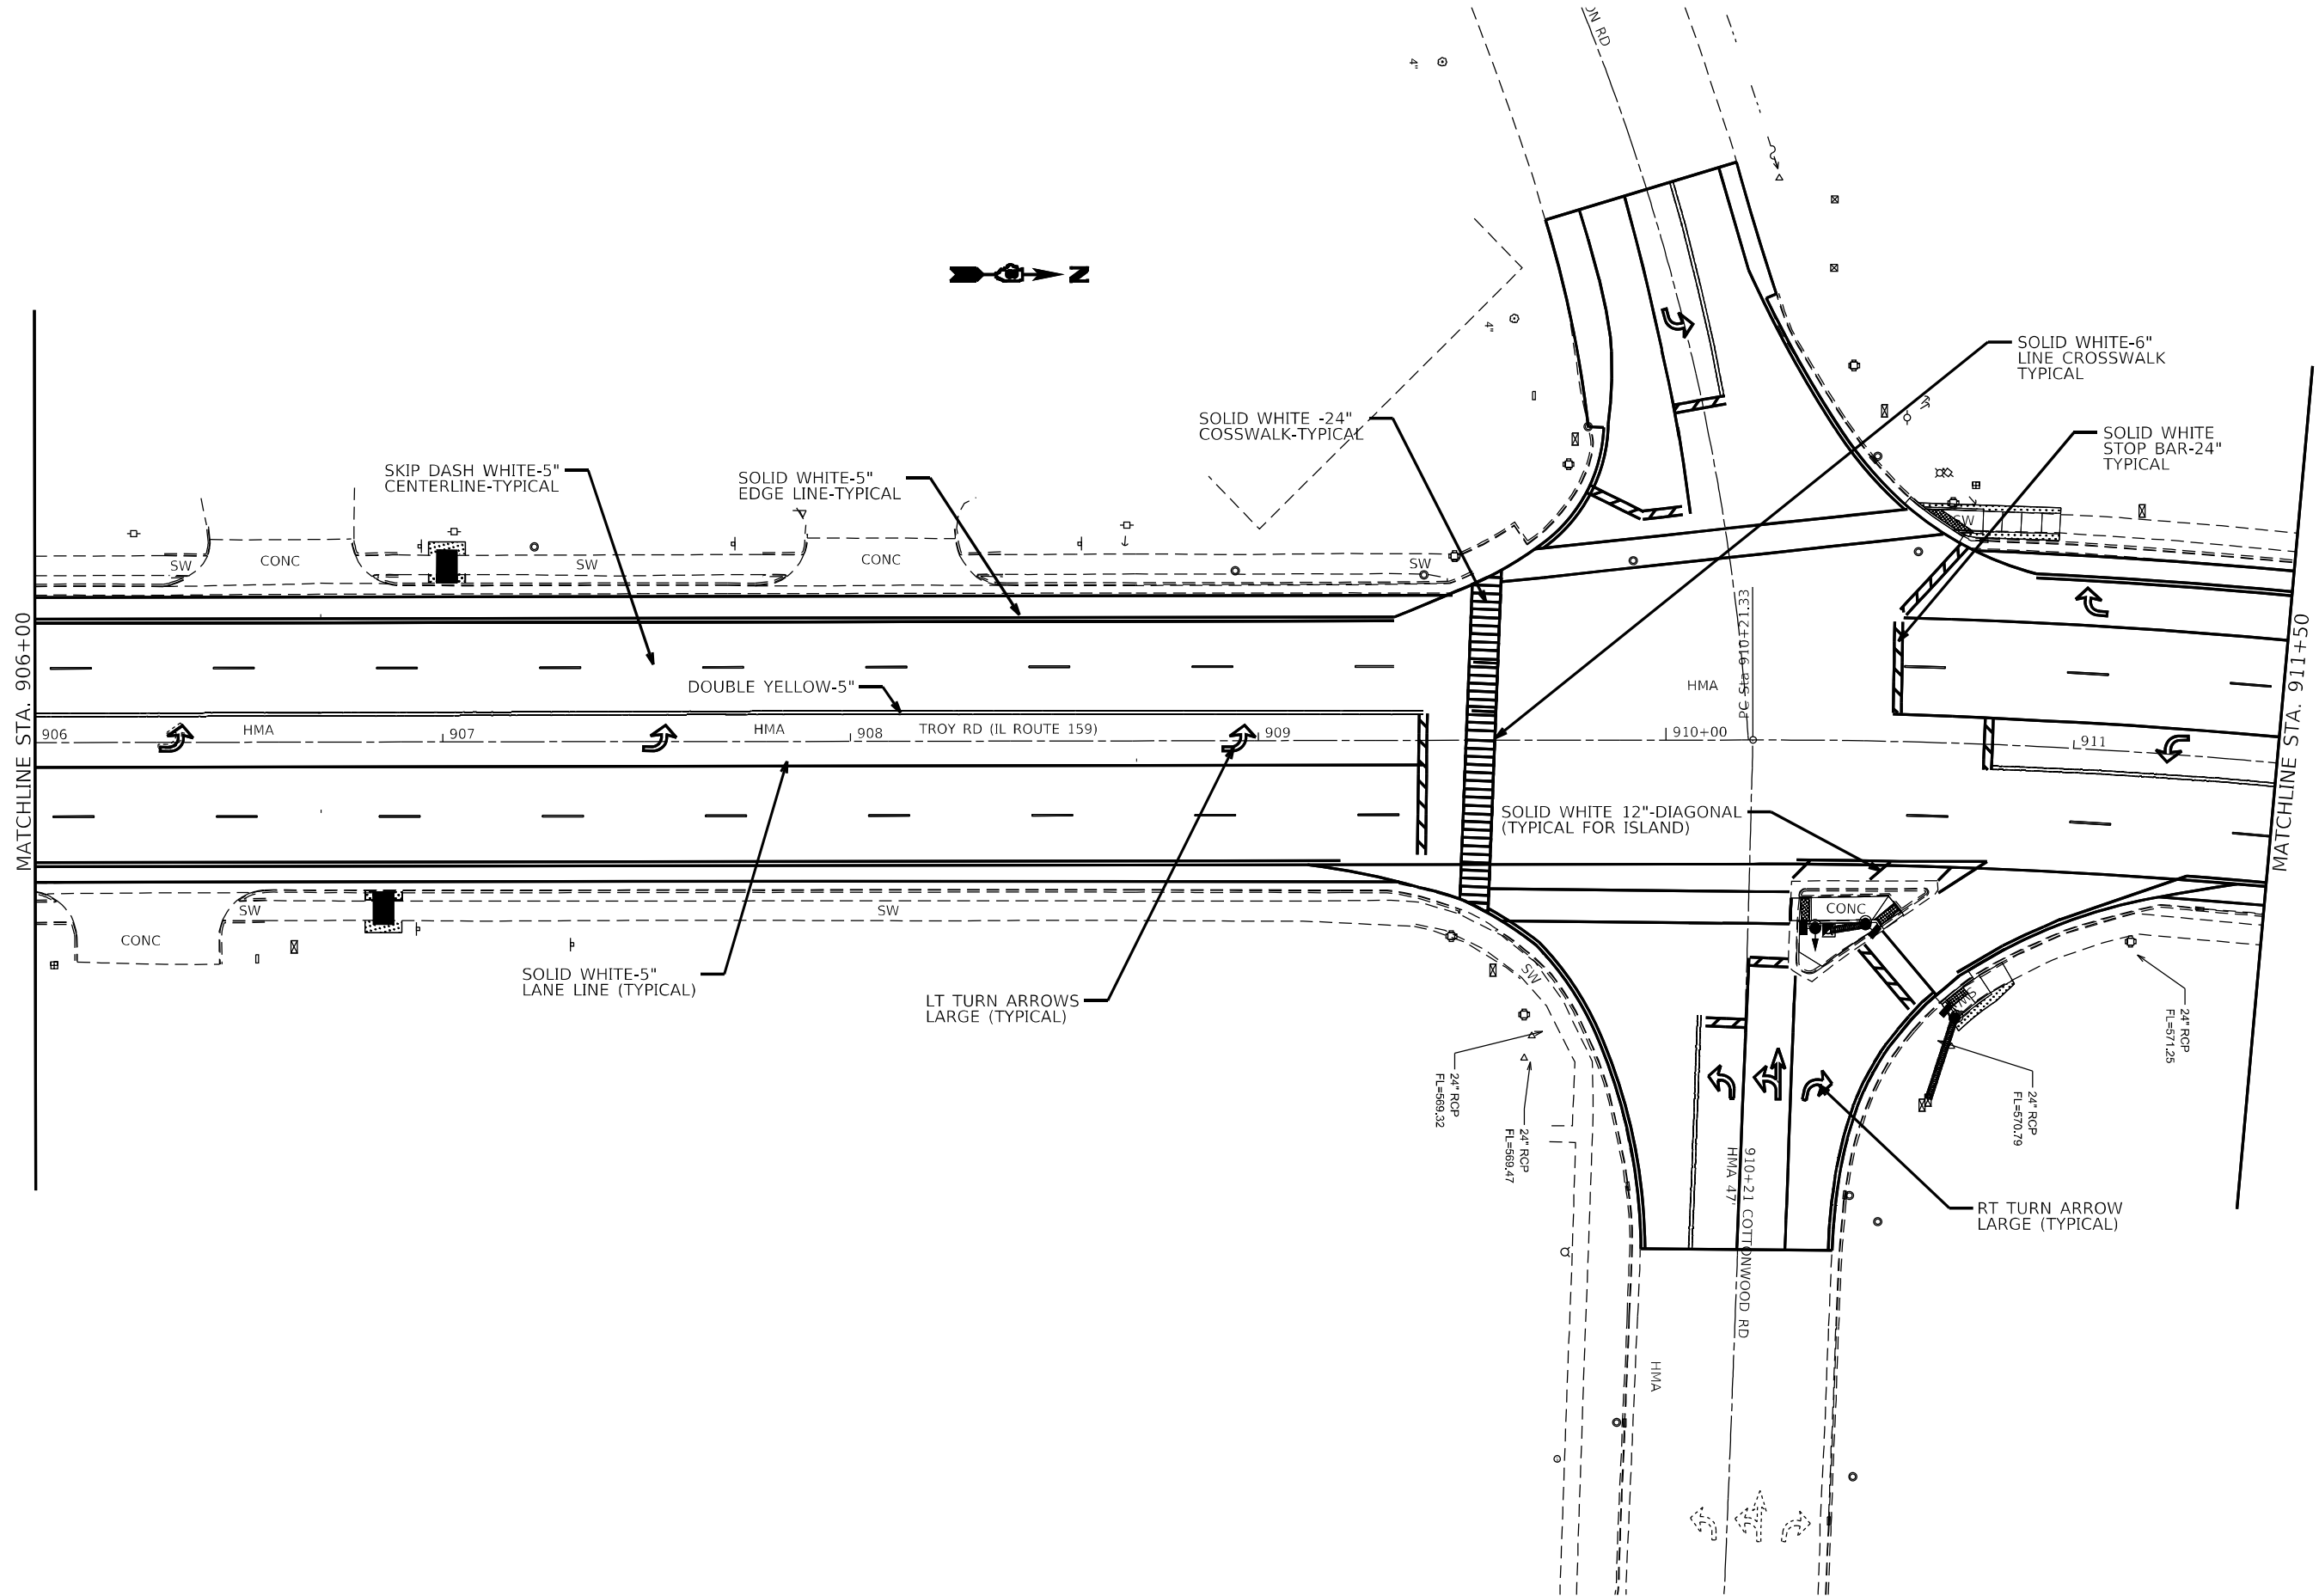


	USER NAME = edison.zo@oryi	DESIGNED -	REVISED -	STATE OF ILLINOIS DEPARTMENT OF TRANSPORTATION	PAVEMENT MARKING				FAP/U RTE.	SECTION	COUNTY	TOTAL SHEETS	SHEET NO.
		DRAWN -	REVISED -						*	(122,122-1,30)/RS-4	MADISON	328	237
	PLOT SCALE = 40,4587 ' / in.	CHECKED -	REVISED -						CONTRACT NO. 76M87				
	PLOT DATE = 10/26/2022	DATE -	REVISED -		SCALE: 1:20		SHEET 57	OF 64 SHEETS	STA.	TO STA.			
									ILLINOIS		FED. AID PROJECT		

MODEL: ANODELX.MXS
FILE: \\nares-pw\illinois\paw\hwy\comp\WIDOT\Documents\DOT_Office\Drawn\81\Project\1026\76M87\CAAD\Drawn\1026\76M87\2410-2022.dgn

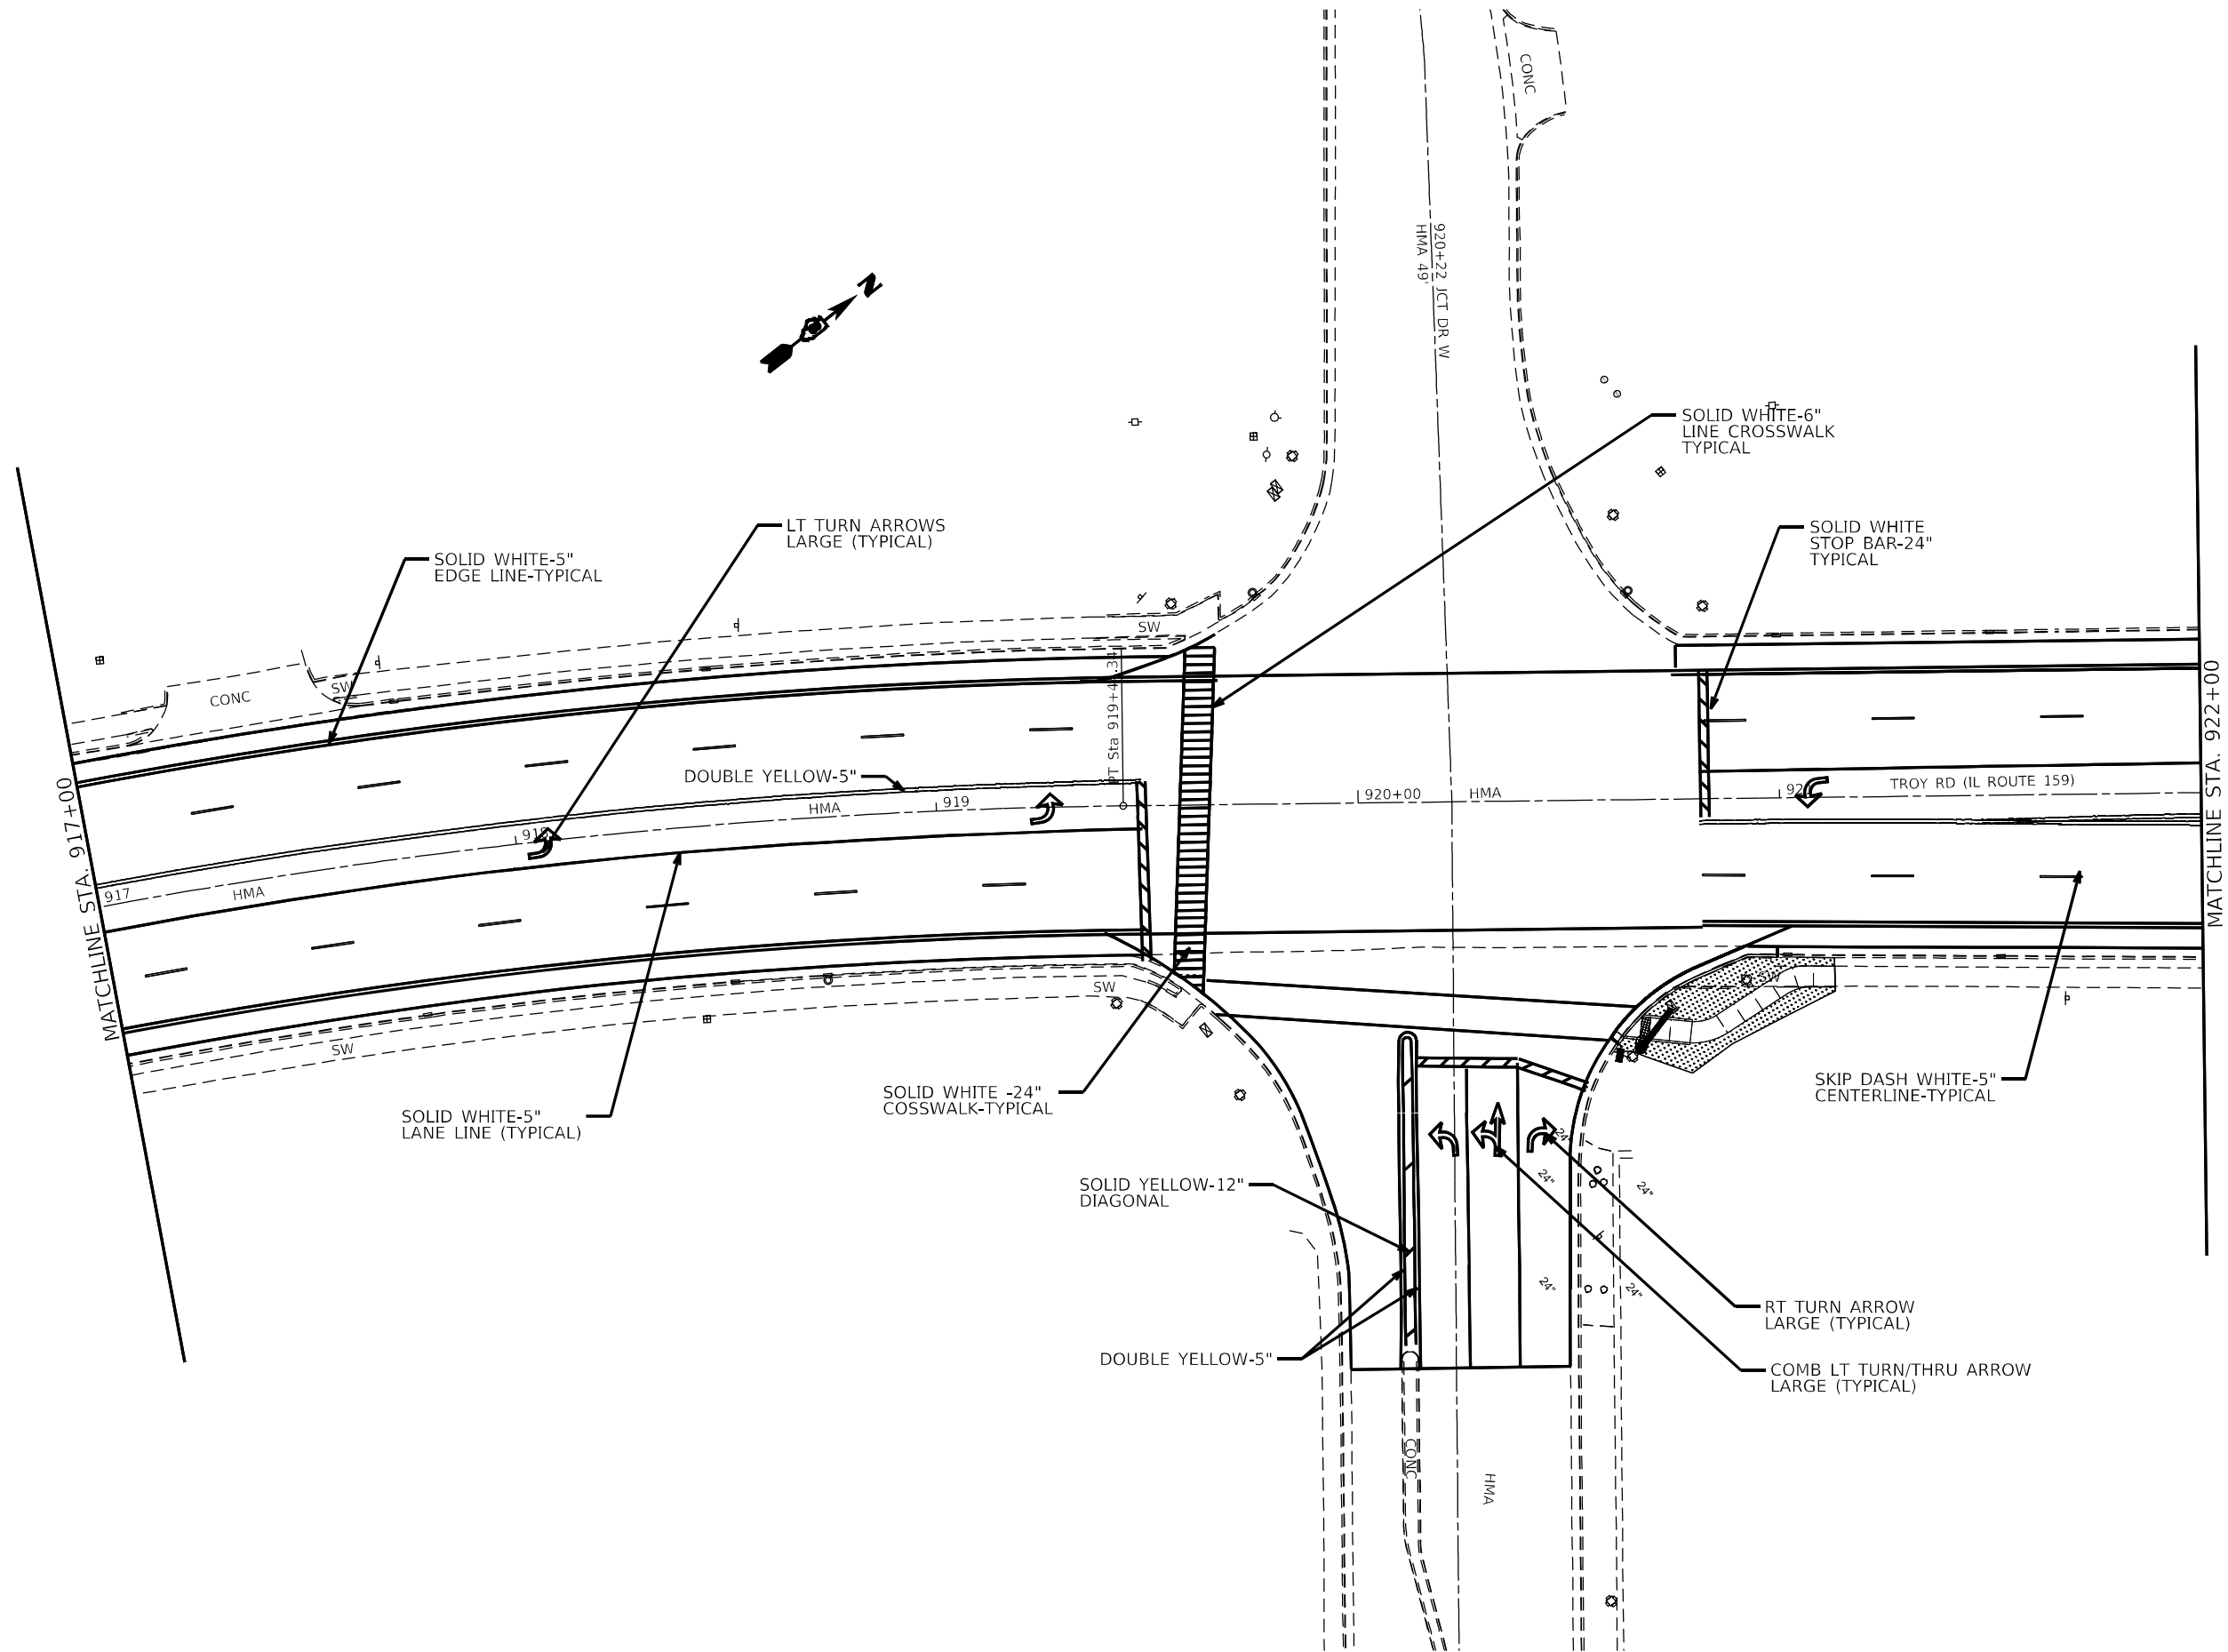

FILE NAME: 10262022.DWG	USER NAME = edison.zo/foryi	DESIGNED -	REVISED -	STATE OF ILLINOIS DEPARTMENT OF TRANSPORTATION	PAVEMENT MARKING				FAP/U RTE.	SECTION	COUNTY	TOTAL SHEETS	SHEET NO.
		DRAWN -	REVISED -						*	(122,122-1,30)RS-4	MADISON	328	239
	PLOT SCALE = 40,4587' / in.	CHECKED -	REVISED -		SCALE: 1:20 SHEET 59 OF 64 SHEETS STA. TO STA.				*600/8887	CONTRACT NO. 76M87			
	PLOT DATE = 10/26/2022	DATE -	REVISED -						ILLINOIS FED. AID PROJECT				

MODEL: ANODELX.MXS
FILE: \\nares-pc\illinois\pavement\concrete\WIDOT\Documents\JUDOT - Office\JUDot\4 - B\Project\JUDOT\BMD\TCA\Data\CAD\Sheet\JUDOT\BMD\7411-001.dgn

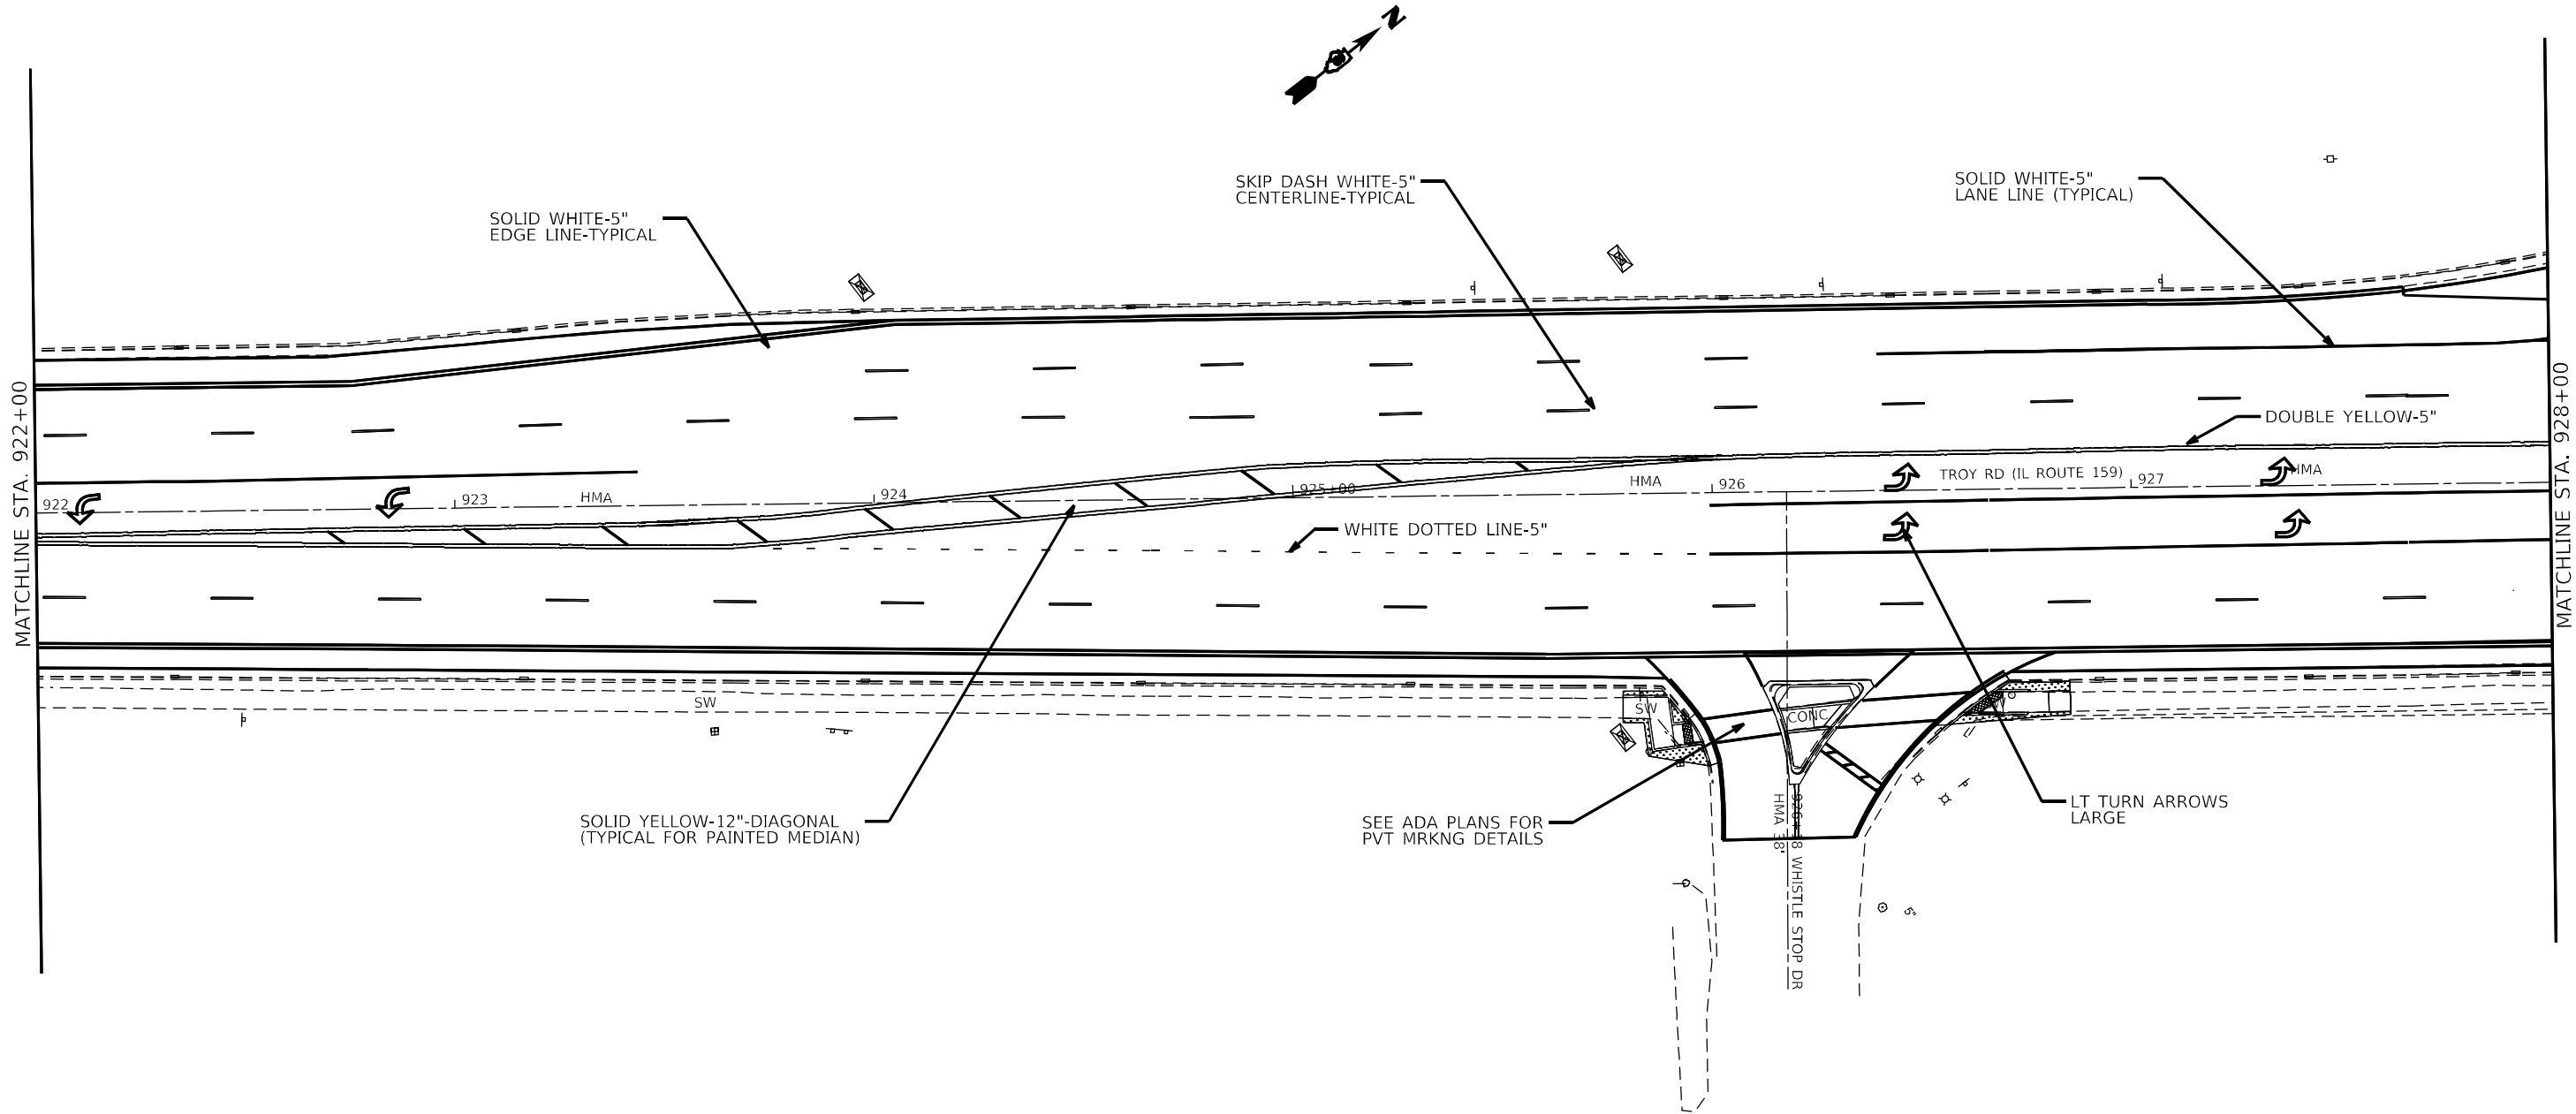

	USER NAME	= edison.zohforyi	DESIGNED	-	REVISED	-
	DRAWN	-	CHECKED	-	REVISED	-
	PLOT SCALE	= 40,4587 ' / in.	DATE	-	REVISED	-
	PLOT DATE	= 10/26/2022				


STATE OF ILLINOIS
DEPARTMENT OF TRANSPORTATION

PAVEMENT MARKING

SCALE: 1:20 SHEET 60 OF 64 SHEETS STA. TO STA.


FAP/U RTE.	SECTION	COUNTY	TOTAL SHEETS	SHEET NO.
*	(122,122-1,30)/RS-4	MADISON	328	240
*600/8887		CONTRACT NO. 76M87		
ILLINOIS		FED. AID PROJECT		

MODEL: ANODEL.MXD
FILE: \\nares-pc\illinois\pavement\Documents\DOT Office\Drawings\818\Project\DOT\818MET\CAD\Drawings\DOT\818MET\818MET.dwg

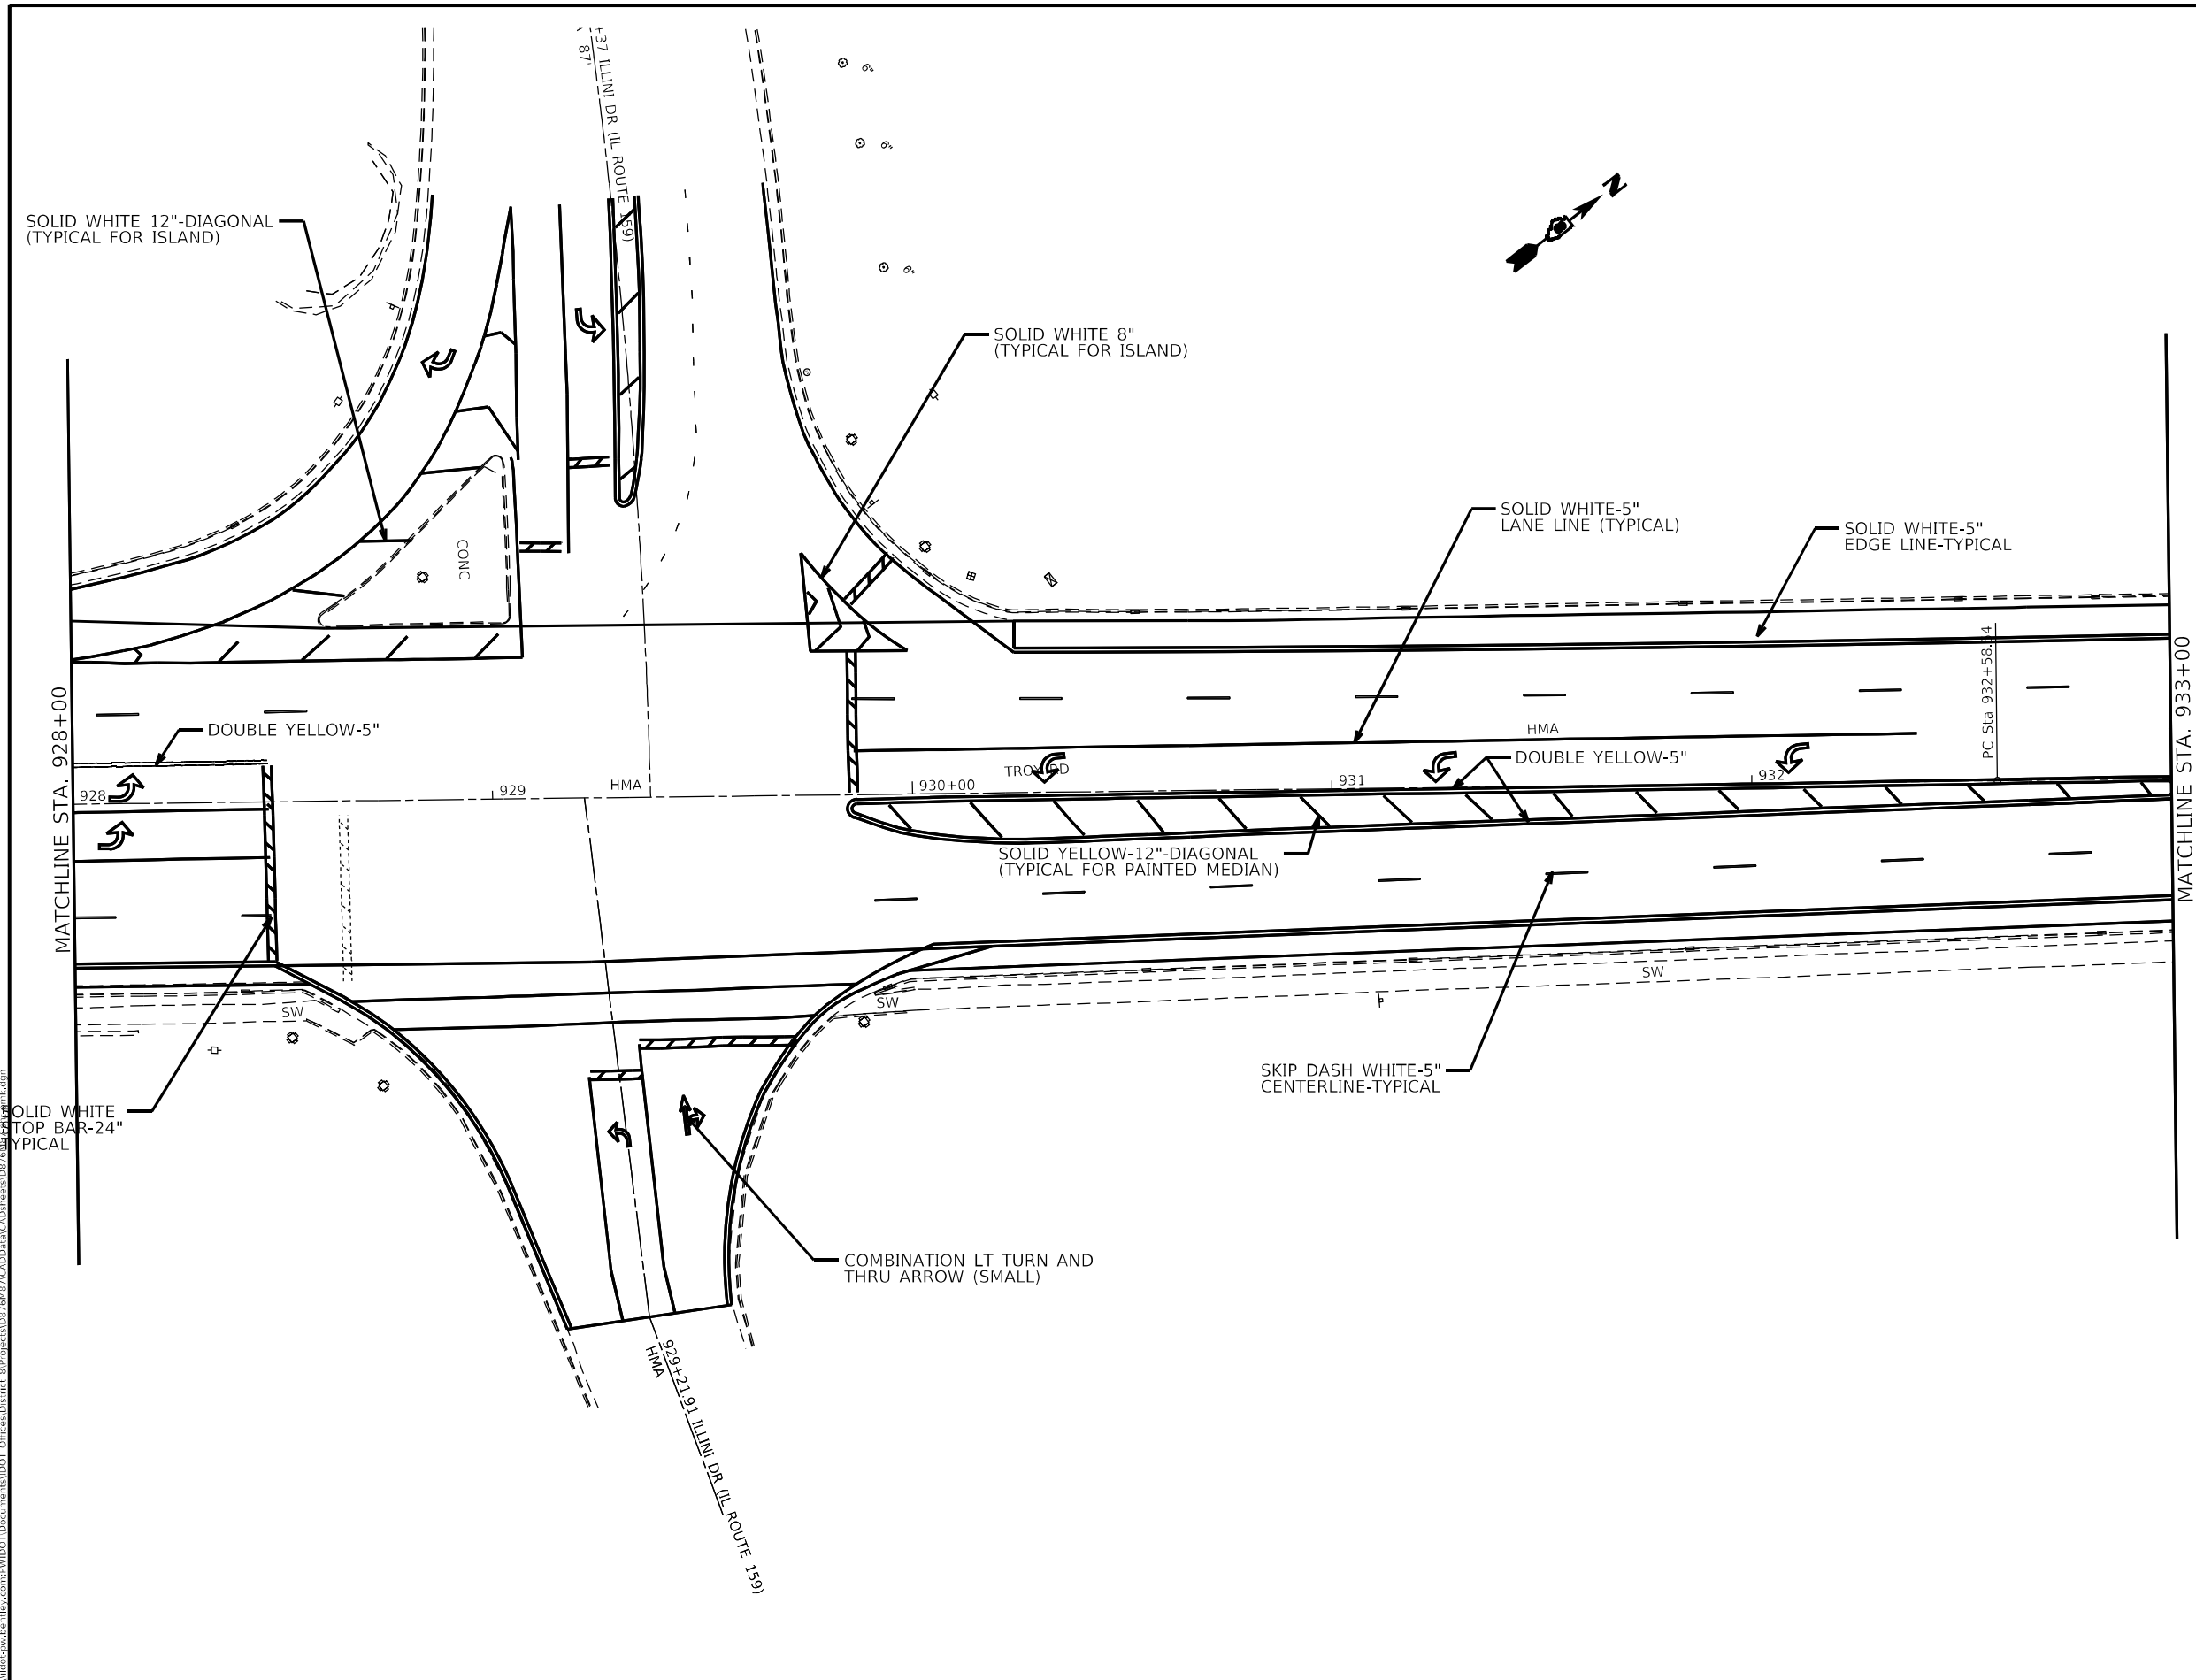

FILE NAME: 102622	USER NAME = edison.zohforyi	DESIGNED -	REVISED -	STATE OF ILLINOIS DEPARTMENT OF TRANSPORTATION	PAVEMENT MARKING				FAP/U RTE.	SECTION	COUNTY	TOTAL SHEETS	SHEET NO.
		DRAWN -	REVISED -						*	(122,122-1,30)RS-4	MADISON	328	241
	PLOT SCALE = 40,4587' / in.	CHECKED -	REVISED -						CONTRACT NO. 76M87				
	PLOT DATE = 10/26/2022	DATE -	REVISED -										
					SCALE: 1:20	SHEET 61	OF 64 SHEETS	STA.	TO STA.				

MODEL: ANODELX.MXS
FILE: \\VMS-PAV\illinois\pav\hwy\comp\WIDOT\Documents\JUDOT_Office\JUDot14_8\Project\JUDOT\WIDOT\CAD\Drawings\JUDOT\WIDOT\241b-pml.dgn

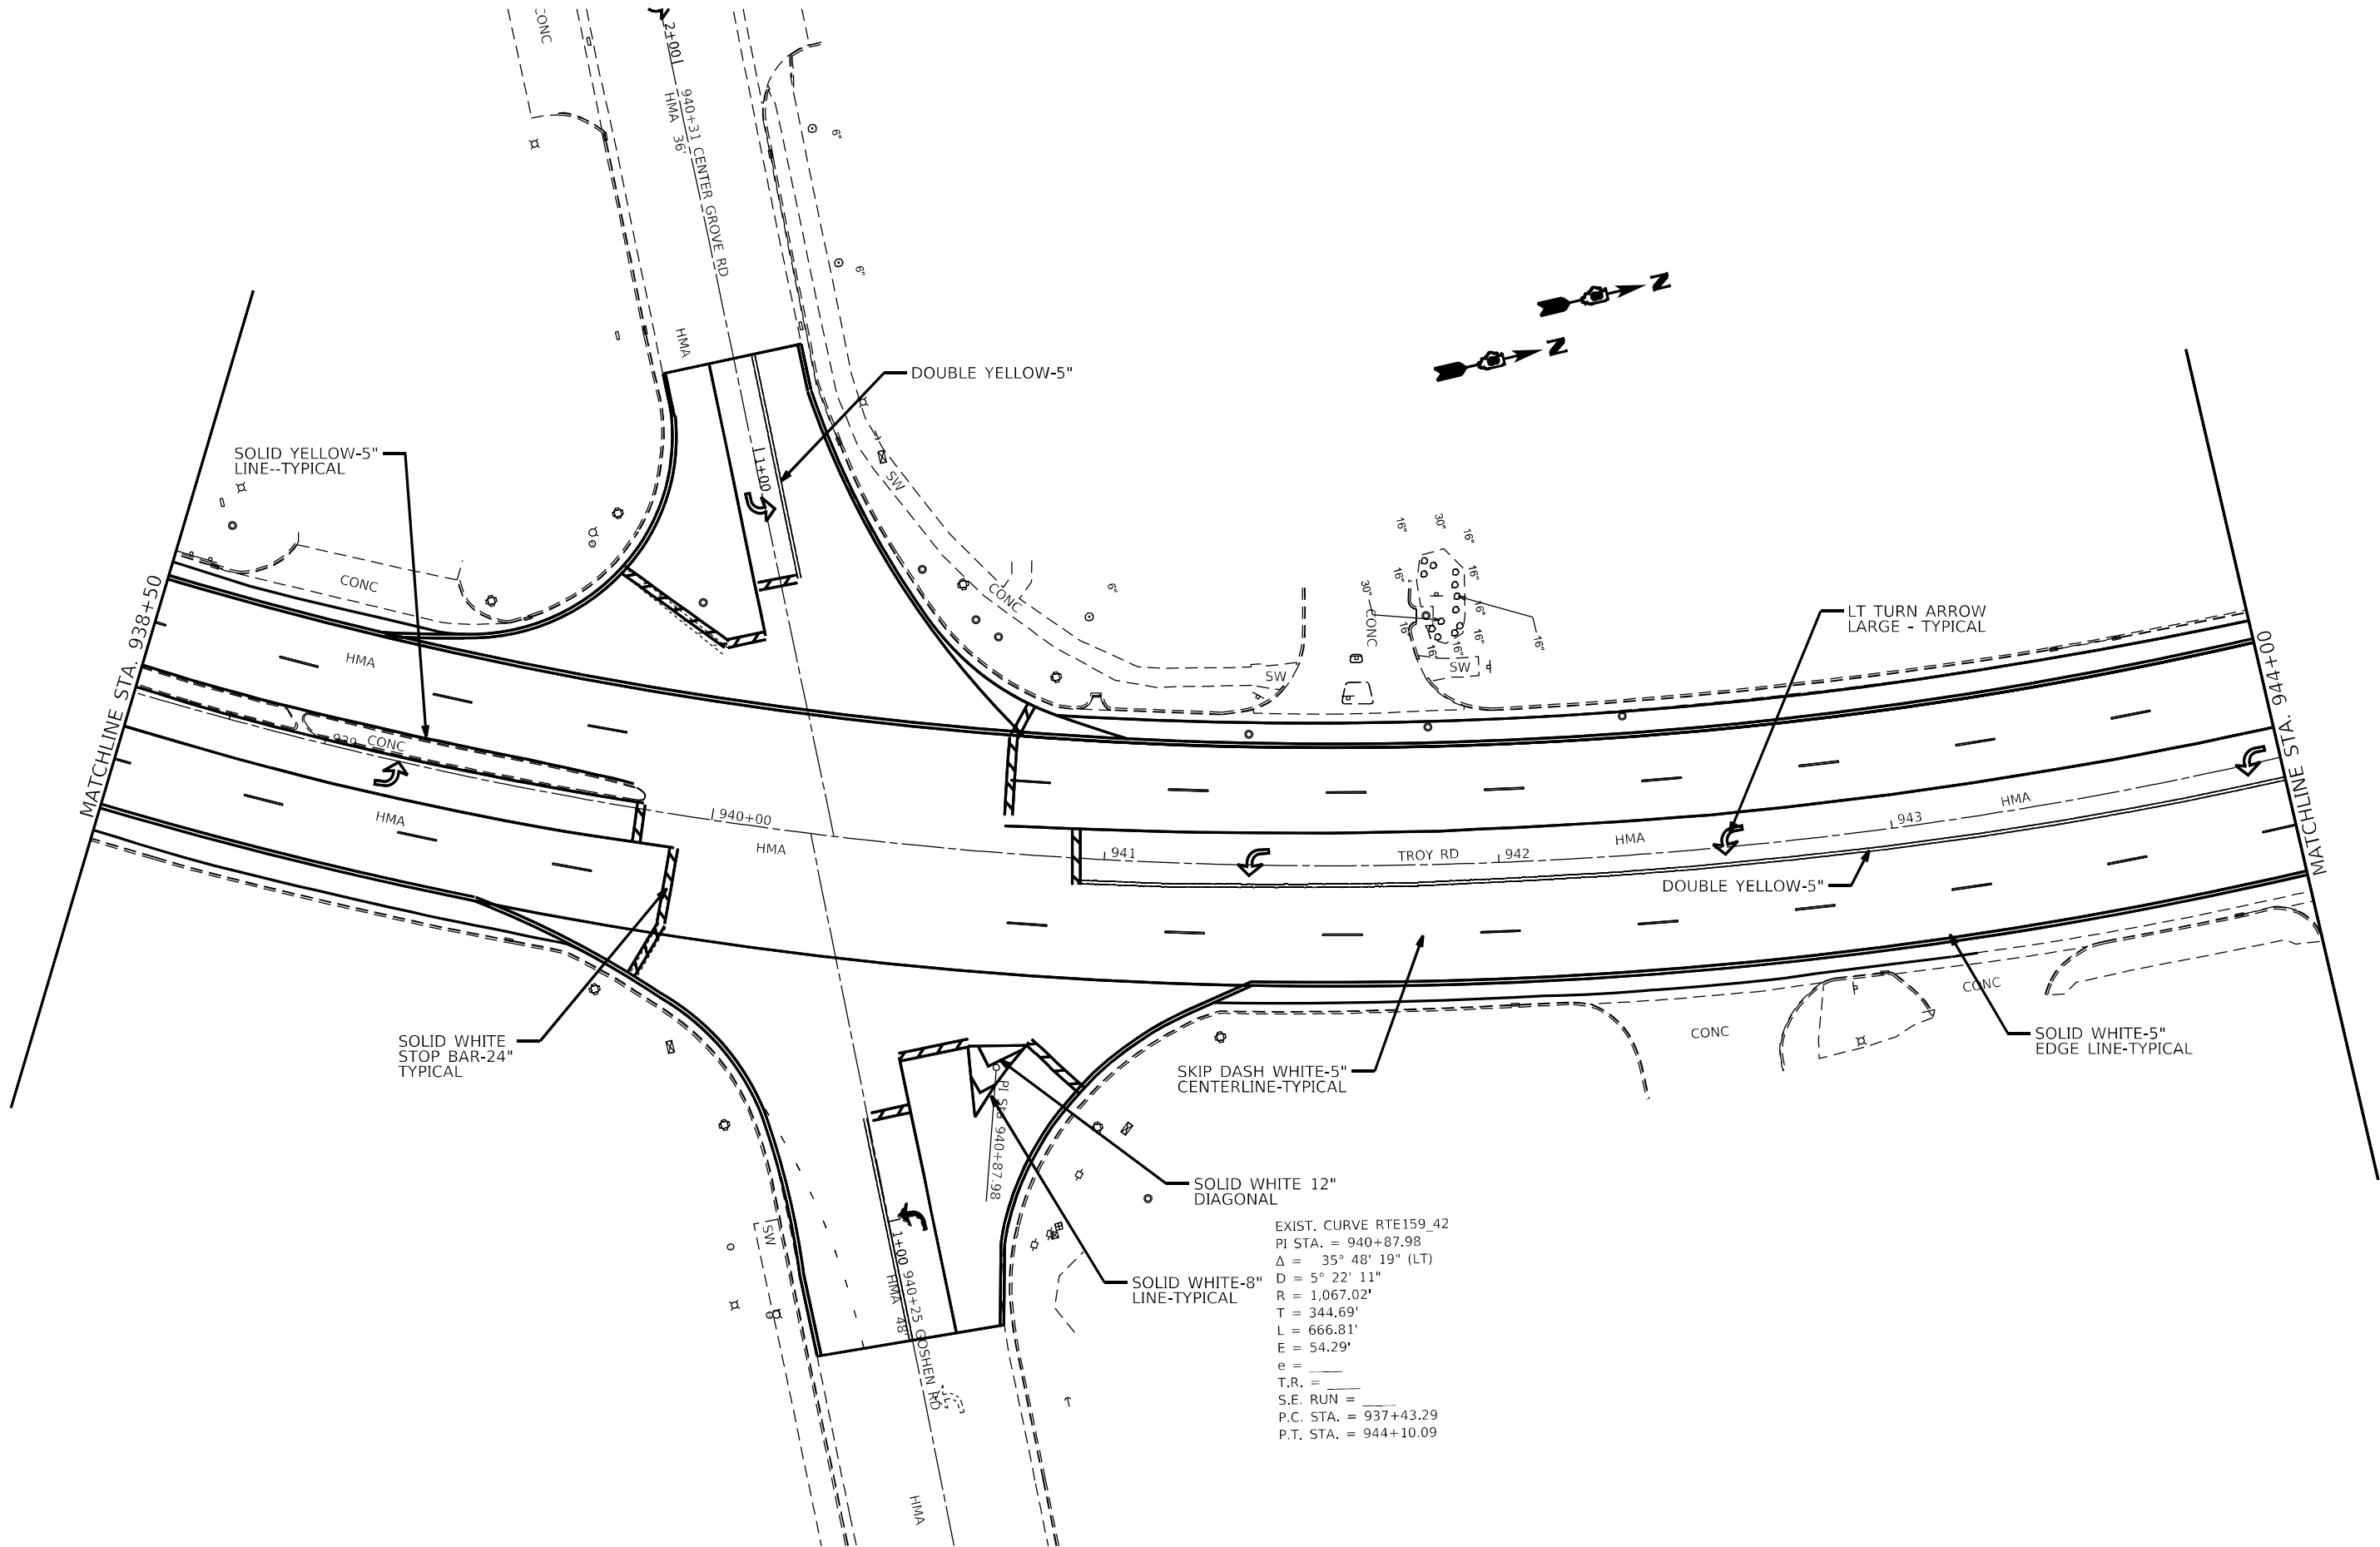

EXIST. CURVE RTE159_42
PI STA. = 940+87.98
 Δ = 35° 48' 19" (LT)
D = 5° 22' 11"
R = 1,067.02'
T = 344.69'
L = 666.81'
E = 54.29'
e = _____
T.R. = _____
S.E. RUN = _____
P.C. STA. = 937+43.29
P.T. STA. = 944+10.09

	USER NAME = edison.zohforyi		DESIGNED -	REVISED -	STATE OF ILLINOIS DEPARTMENT OF TRANSPORTATION	PAVEMENT MARKING				FAP/U RTE.	SECTION	COUNTY	TOTAL SHEETS	SHEET NO.
			DRAWN -	REVISED -						*	(122,122-1,30)/RS-4	MADISON	328	243
	PLOT SCALE = 40,4587' / in.		CHECKED -	REVISED -						*600/8887		CONTRACT NO. 76M87		
	PLOT DATE = 10/26/2022		DATE -	REVISED -		SCALE: 1:20	SHEET 63	OF 64	SHEETS	STA.	TO STA.		ILLINOIS FED. AID PROJECT	

TRAFFIC SIGNAL GENERAL NOTES

1.

PRIOR TO COMMENCING CONSTRUCTION OF ANY COMPONENT OF THE PROPOSED TRAFFIC SIGNAL SYSTEM, ALL UNDERGROUND UTILITIES SHALL BE FIELD LOCATED ACCORDING TO ARTICLE 107.39 OF THE "STANDARD SPECIFICATIONS FOR ROAD AND BRIDGE CONSTRUCTION". AGENCIES KNOWN TO HAVE FACILITIES WITHIN THE PROJECT LIMITS ARE LISTED IN THE GENERAL NOTES OF THE PLANS.
2.

ALL EXISTING SIGNAL HEADS BEING RELOCATED TO A NEW LOCATION SHALL USE NEW STAINLESS STEEL MOUNTING BANDS.
3.

MOUNTING HARDWARE, EXCEPT WHERE NOTED, SHALL BE UNPAINTED ALUMINUM. ALL BOLTS, SCREWS, NUTS, AND WASHERS SHALL BE STAINLESS STEEL. ANTI -SEIZE PASTE COMPOUND SHALL BE USED ON ALL MOUNTING HARDWARE FIELD CONNECTIONS.
4.

AT THE INTERSECTIONS OF GLEN CARBON/COTTONWOOD ROAD, JUNCTION DRIVE, AND ILLINI DRIVE, MOUNTING HARDWARE SHALL BE PAINTED BLACK ALUMINUM. ALL BOLTS, SCREWS, NUTS, AND WASHERS SHALL BE STAINLESS STEEL. ANTI -SEIZE PASTE COMPOUND SHALL BE USED ON ALL MOUNTING HARDWARE FIELD CONNECTIONS.
5.

BACK PLATES SHALL BE ABS PLASTIC.
6.

ALL TRAFFIC SIGNAL CABLES SHALL BE #14 AWG STRANDED COPPER UNLESS OTHERWISE SPECIFIED. TERMINAL ENDS SHALL HAVE CRIMPED-ON RING TONGUE CONNECTORS.
7.

THE PROPOSED LOCATION OF SIGNAL HEADS ON MAST ARMS SHALL BE APPROVED BY THE ENGINEER BEFORE INSTALLATION.
8.

NO SURVEY WAS PERFORMED FOR THE TRAFFIC SIGNAL PLANS. THE TRAFFIC SIGNAL PLANS WERE CREATED USING AERIAL IMAGERY AND FIELD MEASUREMENTS.
9.

 
QUANTITIES SHOWN FOR PROPOSED TRAFFIC SIGNAL HEADS ASSUME THAT THE TRAFFIC SIGNAL CABLE IN CONDUIT WILL BE INSTALLED IN EXISTING CONDUIT AND VARIOUS EXISTING TRAFFIC SIGNAL EQUIPMENT.
10.

IF THERE IS NOT SUFFICIENT SLACK TO RELOCATE EXISTING SIGNAL HEADS, PEDESTRIAN SIGNAL HEADS, OR PUSH BUTTONS; REMOVE ELECTRIC CABLE FROM CONDUIT QUANTITY HAS BEEN INCLUDED TO REMOVE THE TRAFFIC SIGNAL CABLE ONLY FOR THE RESPECTIVE EQUIPMENT AND INSTALL NEW TRAFFIC SIGNAL CABLE IN THE EXISTING CONDUIT.
11.

EXISTING NO. 6, EQUIPMENT GROUNDING CABLE IS NOT INTENDED TO BE REMOVED WITH SIGNAL CABLE WHEN RELOCATING TRAFFIC SIGNAL EQUIPMENT.
12.

EXISTING OVERHEAD SIGN PANELS MAY NEED TO BE ADJUSTED DUE TO THE RELOCATION OF SIGNAL HEADS. ADJUSTING THE EXISTING SIGN PANELS SHALL BE CONSIDERED AS INCLUDED IN THE CONTRACT UNIT PRICE FOR SIGNAL HEAD RELOCATION.

TRAFFIC SIGNAL LEGEND


	PROPOSED SIGNAL HEAD WITH BACKPLATE (SEE HIGHWAY STANDARD 880006)
	PROPOSED SIGNAL HEAD WITHOUT BACKPLATE (SEE HIGHWAY STANDARD 880006)
	EXISTING SIGNAL HEAD WITH BACKPLATE
	EXISTING SIGNAL HEAD WITHOUT BACKPLATE
	EXISTING HANDHOLE
	EXISTING DOUBLE HANDHOLE
	EXISTING DETECTOR LOOP (SEE HIGHWAY STANDARDS 886001 & 886006)
	EXISTING CONDUIT
	EXISTING MAST ARM
	EXISTING SIGNAL HEAD, PEDESTRIAN
	EXISTING PEDESTRIAN PUSH BUTTON DETECTOR
	EXISTING CONTROLLER
	EXISTING SIGNAL POST
	PROPOSED SIGNAL HEAD, PEDESTRIAN
	PROPOSED APS PEDESTRIAN PUSH BUTTON
	PROPOSED PEDESTRIAN PUSH BUTTON POST

TRAFFIC SIGNAL BILL OF MATERIALS

CODE NO.	ITEM	UNIT	TOTAL QUANTITIES
72000100	SIGN PANEL - TYPE 1	SQ FT	43.2
81028340	UNDERGROUND CONDUIT, PVC, 1 1/2" DIA.	FOOT	141
81028370	UNDERGROUND CONDUIT, PVC, 3" DIA.	FOOT	106
81400100	HANDHOLE	EACH	1
87301215	ELECTRIC CABLE IN CONDUIT, SIGNAL NO. 14 2C	FOOT	2866
87301225	ELECTRIC CABLE IN CONDUIT, SIGNAL NO. 14 3C	FOOT	1400
87301245	ELECTRIC CABLE IN CONDUIT, SIGNAL NO. 14 5C	FOOT	7485
87301255	ELECTRIC CABLE IN CONDUIT, SIGNAL NO. 14 7C	FOOT	155
87301900	ELECTRIC CABLE IN CONDUIT, EQUIPMENT GROUNDING CONDUCTOR, NO. 6	FOOT	683
87502230	TRAFFIC SIGNAL POST, PAINTED STEEL 8 FT.	EACH	2
87502620	TRAFFIC SIGNAL POST, ALUMINUM 8 FT.	EACH	2
87800100	CONCRETE FOUNDATION, TYPE A	FOOT	38
88040090	SIGNAL HEAD, POLYCARBONATE, LED, 1-FACE, 3-SECTION, MAST ARM MOUNTED	EACH	13
88040150	SIGNAL HEAD, POLYCARBONATE, LED, 1-FACE, 5-SECTION, BRACKET MOUNTED	EACH	1
88102825	PEDESTRIAN SIGNAL HEAD, POLYCARBONATE, LED, 1-FACE, BRACKET MOUNTED WITH COUNT DOWN TIMER	EACH	40
88200510	TRAFFIC SIGNAL BACKPLATE, RETROREFLECTIVE	EACH	13
89500100	RELOCATE EXISTING SIGNAL HEAD	EACH	25
89501150	RELOCATE EXISTING TRAFFIC SIGNAL POST	EACH	1
89502200	MODIFY EXISTING CONTROLLER	EACH	13
89502300	REMOVE ELECTRIC CABLE FROM CONDUIT	FOOT	7028
89502375	REMOVE EXISTING TRAFFIC SIGNAL EQUIPMENT	EACH	8
89502385	REMOVE EXISTING CONCRETE FOUNDATION	EACH	1
X8140205	MODIFY EXISTING CONCRETE HANDHOLE	EACH	15
X8760200	ACCESSIBLE PEDESTRIAN SIGNALS	EACH	48
X8760201	PEDESTRIAN PUSH-BUTTON POST	EACH	14

STANDARDS FOR TRAFFIC SIGNAL SHEETS

720001	SIGN PANEL MOUNTING DETAILS
873001	TRAFFIC SIGNAL GROUNDING & BONDING
878001	CONCRETE FOUNDATION DETAILS
880006	TRAFFIC SIGNAL MOUNTING DETAILS

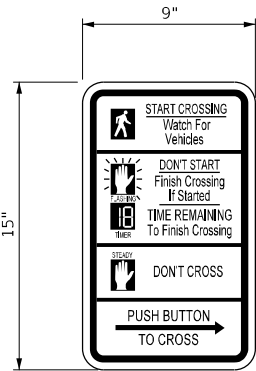

ACCESSIBLE PEDESTRIAN SIGNAL SIGN
R10-3e

B

MODEL: \\MODEL\\NAMES
FILE: \\NAMES\\projects\\76M87\\CAD\\Data\\CAD\\sheets\\HMG\\2022-10-24\\0376M87-sh-25_Gen_Notes.dgn

HMG ENGINEERS IL PROF DESIGN FIRM 184,000899	USER NAME = Default	DESIGNED -	REVISED -	STATE OF ILLINOIS DEPARTMENT OF TRANSPORTATION	TRAFFIC SIGNAL SHEETS				F.A.P. RTE.	SECTION	COUNTY	TOTAL SHEETS	SHEET NO.
		DRAWN -	REVISED -						600	(122,122-1.30)RS-4	MADISON	328	245
	PLOT SCALE = 10,0000 ' / in.	CHECKED -	REVISED -						CONTRACT NO. 76M87				
	PLOT DATE = 10/26/2022	DATE -	REVISED -		SCALE: NTS	SHEET TS 1 OF 31 SHEETS	STA.	TO STA.	ILLINOIS FED. AID PROJECT				

TRAFFIC SIGNAL


INTERSECTION	UNDRGRD C PVC 1 1/2	UNDRGRD C PVC 3	ELCBL C EGRDC 6 1C	ELCBL C SIGNAL 14 2C	ELCBL SIGNAL 14 3C	ELCBL C SIGNAL 14 5C	ELCBL C SIGNAL 14 7C	SH P LED 1F 3S MAM	SH P LED 1F 5S BM	PED SH P LED 1F BM CT	TS BACKPLATE RET-REFL	RELOC EX SIG HEAD
	(FOOT)	(FOOT)	(FOOT)	(FOOT)	(FOOT)	(FOOT)	(FOOT)	(EACH)	(EACH)	(EACH)	(EACH)	(EACH)
E COUNTRY LN						898		2			2	2
ST. CHARLES DR						798		2			2	2
I-55/70 N JCT						159						2
MARYVILLE TOWN CENTER						934						4
MAIN ST	34		78	1078		732		2		8	2	2
VADALABENE DR	27	101	168	633	433	710		1		4	1	3
IL ROUTE 162						797	155	2	1	8	2	2
GLEN CROSSING RD	8		19	514	425	769		2		6	2	2
I-270 S JCT						970		1			1	3
I-270 N JCT						621		1			1	2
GLEN CARBON /COTTONWOOD RD	31	5	72	256	256	97				8		1
JUNCTION DR	33		322	348	286					4		
ILLINI DR	8		24	37						2		
TOTAL	141	106	683	2,866	1,400	7,485	155	13	1	40	13	25

TRAFFIC SIGNAL CONTINUED


INTERSECTION	RELOC EX IS POST	MOD EX CONTR	HANDHOLE	REM ELCBL FR CON	REMOVE EX IS EQUIP	MOD EX CONC HANDHOLE	SIGN PANEL TYPE 1	TS POST A 8	TS POST PS 8	REMOV EX CONC FDN	CONC FDN TY A	ACCESTBL F PED SIGNAL	PED PUSHBUTTON POST
	(EACH)	(EACH)	(EACH)	(FOOT)	(EACH)	(EACH)	(SQ FT)	(EACH)	(EACH)	(EACH)	(FOOT)	(EACH)	(EACH)
E COUNTRY LN		1		424									
ST. CHARLES DR		1		375									
I-55/70 N JCT		1		146									
MARYVILLE TOWN CENTER		1		912	1								
MAIN ST		1		1,481	1	4	7.2				10.0	8	4
VADALABENE DR		1		826	1	3	3.6	2			11.0	4	2
IL ROUTE 162		1		373	1		7.2					8	
GLEN CROSSING RD		1		361	1	1	5.4				2.5	6	1
I-270 S JCT		1		846									
I 270 N JCT		1		491									
GLEN CARBON /COTTONWOOD RD	1	1	1	669	1	1	7.2		2	1	9.0	8	
JUNCTION DR		1		75	1	1	3.6				2.5	4	1
ILLINI DR		1		49	1	1	1.8				2.5	2	1
											0.0		
TOTAL	1	13	1	7,028	8	11	36.0	2	2	1	38	40	9

MODEL: s:\MODEL NAMES
FILE: h:\m115-2\m115-2\hwy\dot\Documents\DOT Office\Dir\dir_8\Project\0876487\CADDData\CADDsheets\0876487-shr-schedule_Edison.dgn

	USER NAME = edison,zohfanyi	DESIGNED -	REVISED -	STATE OF ILLINOIS DEPARTMENT OF TRANSPORTATION	SCHEDULE OF QUANTITIES			F.A.P/U RTE.	SECTION	COUNTY	TOTAL SHEETS	SHEET NO.
	DRAWN -	DRAWN -	REVISED -					*	(122,122-1,30)RS-4	MADISON	328	246
	PLOT SCALE = 100,0000 ' / in.	CHECKED -	REVISED -		SCALE:			CONTRACT NO. 76M87				
	PLOT DATE = 10/26/2022	DATE -	REVISED -		SHEET 3 OF 4 SHEETS			ILLINOIS FED. AID PROJECT				

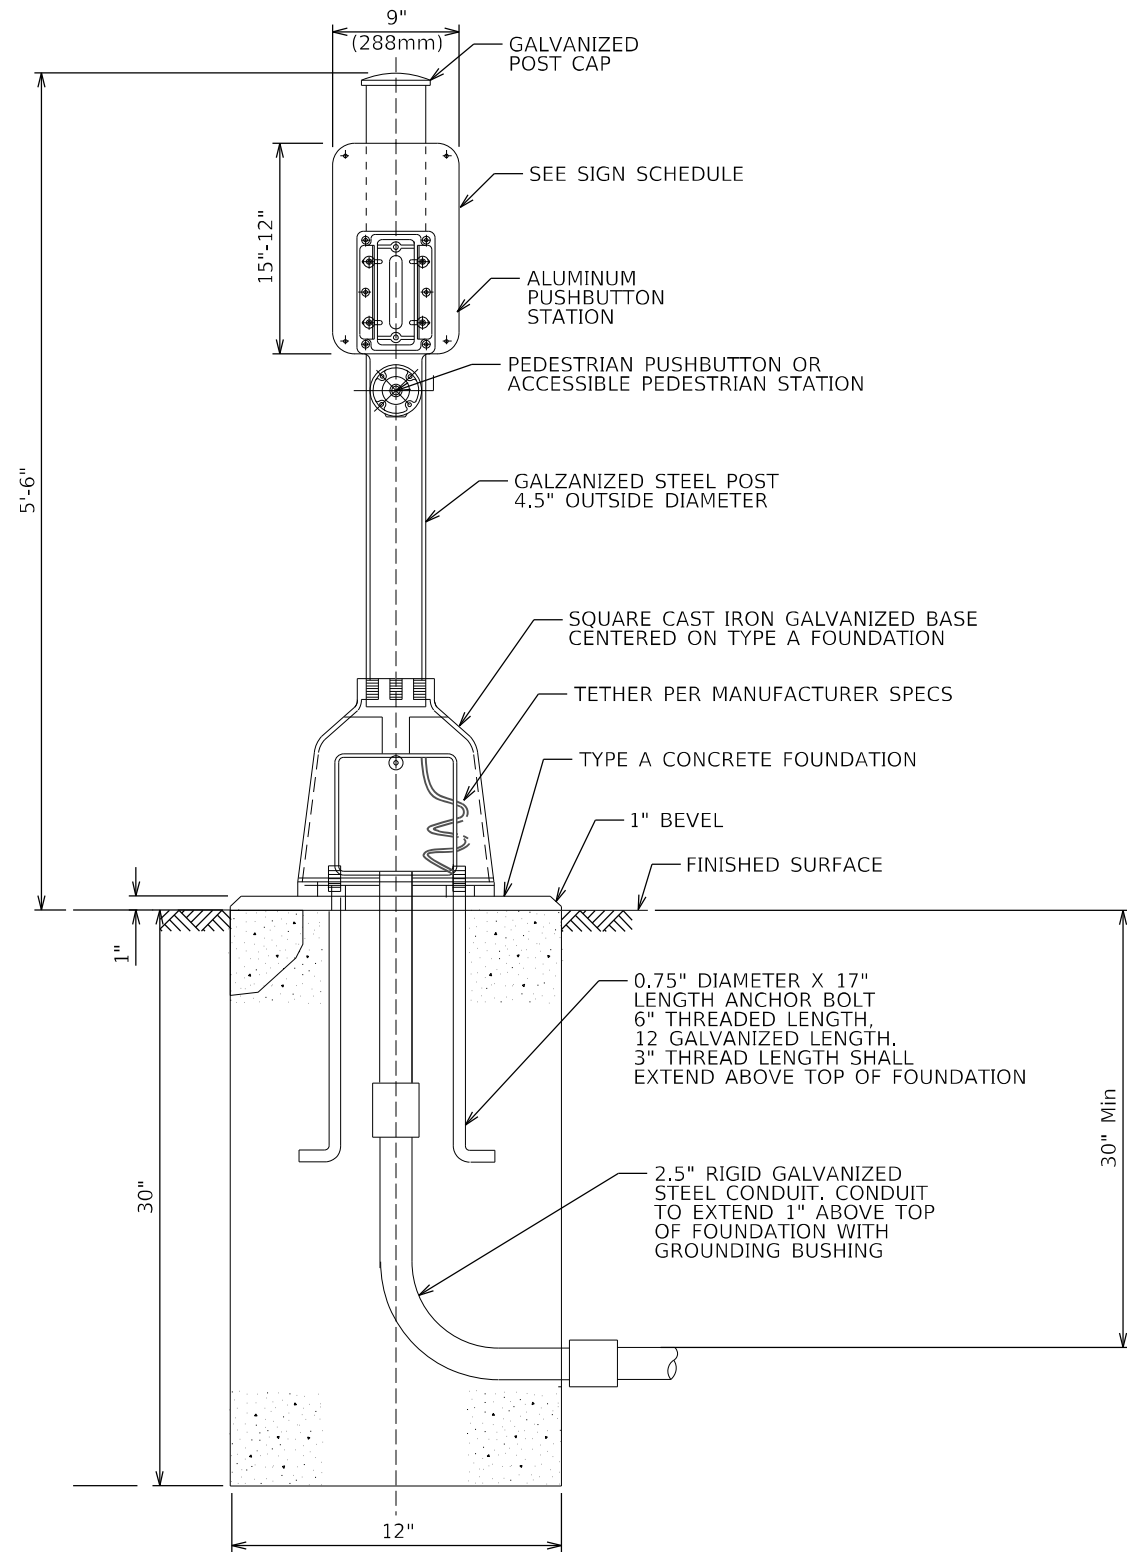


PEDESTRIAN PUSH-BUTTON POST DETAIL
(NOT TO SCALE)

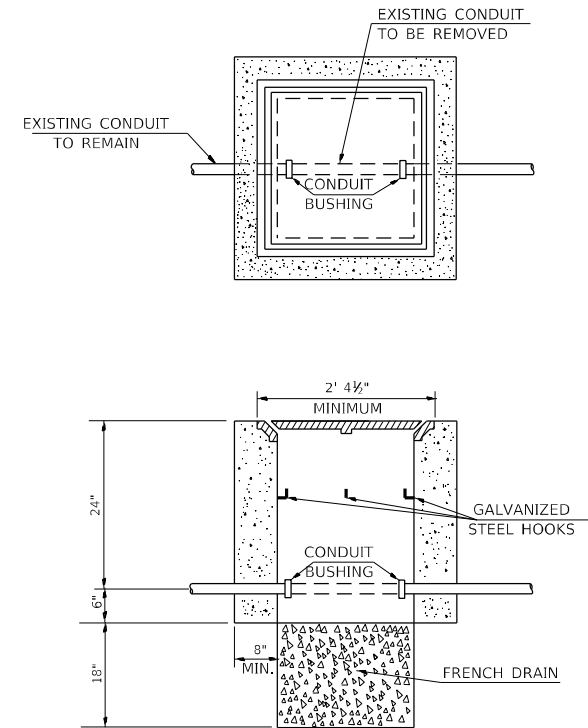

HANDHOLE TO INTERCEPT EXISTING CONDUIT DETAIL
(NOT TO SCALE)

NOTES:

1. REMOVAL OF EXISTING CONDUIT FROM THE HANDHOLE AND THE INSTALLATION OF THE CONDUIT BUSHING SHALL BE INCIDENTAL TO THE HANDHOLE.

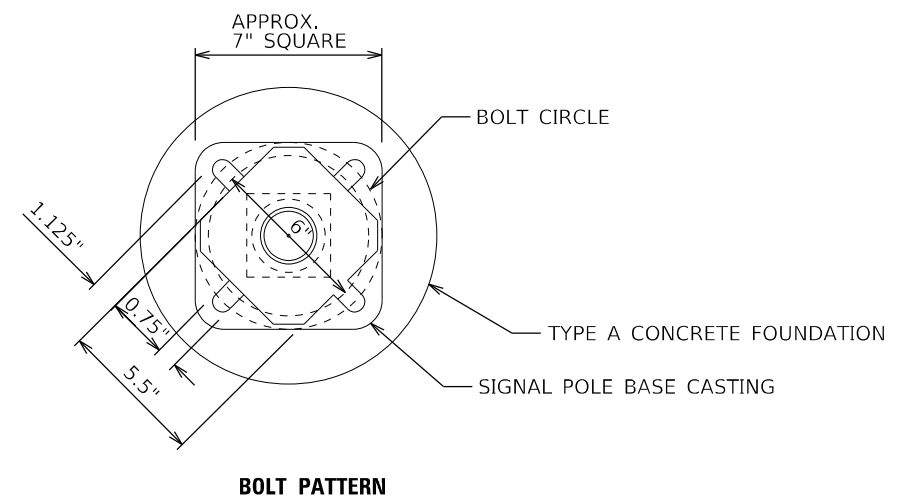

MODEL: Default
FILE NAME: 103248_PTB_199_0218249_010_W01_IL159_Traffic_Signal_Upgrade\Card_Sheets\0876M87_Corst_Det.dgn

HMG
ENGINEERS
IL PROF DESIGN FIRM 184,000899

USER NAME = nseelhoefer	DESIGNED -	REVISED -
	DRAWN -	REVISED -
PLOT SCALE = 40,0000 ' / in.	CHECKED -	REVISED -
PLOT DATE = 6/30/2022	DATE -	REVISED -

**STATE OF ILLINOIS
DEPARTMENT OF TRANSPORTATION**

**TRAFFIC SIGNAL
CONSTRUCTION DETAILS**


SCALE: NTS SHEET 1 OF 1 SHEETS STA. TO STA.

F.A.P. RTE.	SECTION	COUNTY	TOTAL SHEETS	SHEET NO.
600	(122,122-1,30)RS-4	MADISON	328	247
CONTRACT NO. 76M87				
ILLINOIS FED. AID PROJECT				

DELETE

FROM

THIS PROJECT

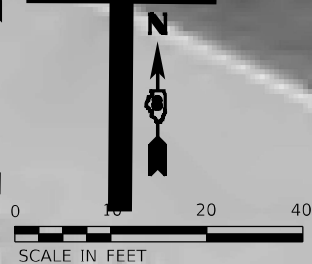

MODEL NAME: 10/26/2022
FILE: 10/26/2022
PROJECT: 10/26/2022
SHEET: 10/26/2022
CONTRACT: 10/26/2022
SHEET NO.: 10/26/2022
SHEET TOTAL: 10/26/2022



USER NAME	= Default	DESIGNED	-	REVISED	-
PLOT SCALE	= 20,000' / in.	DRAWN	-	REVISED	-
PLOT DATE	= 10/26/2022	CHECKED	-	REVISED	-
		DATE	-	REVISED	-


STATE OF ILLINOIS
DEPARTMENT OF TRANSPORTATION

TRAFFIC SIGNAL PLANS
IL ROUTE 159 & BELTLINE ROAD /PINE LAKE ROAD


SCALE: 1" = 10' SHEET TS 2 OF 31 SHEETS STA. TO STA.

F.A.P. RTE.	SECTION	COUNTY	TOTAL SHEETS	SHEET NO.
600	(122,122-1,30)RS-4	MADISON	228	248
CONTRACT NO. 76M87				
ILLINOIS FED. AID PROJECT				

The word "DELETED" is written in large, bold, black, sans-serif capital letters across the top of the page. The background consists of various technical or architectural drawings, including lines, curves, and labels such as "NO 14, 5/C", "LD-IN, NO 14, 2/C", "IL ROUTE 1", and "No 14". There are also small circular markers and a dashed rectangular box containing a crosshair-like symbol on the left side of the drawing area.

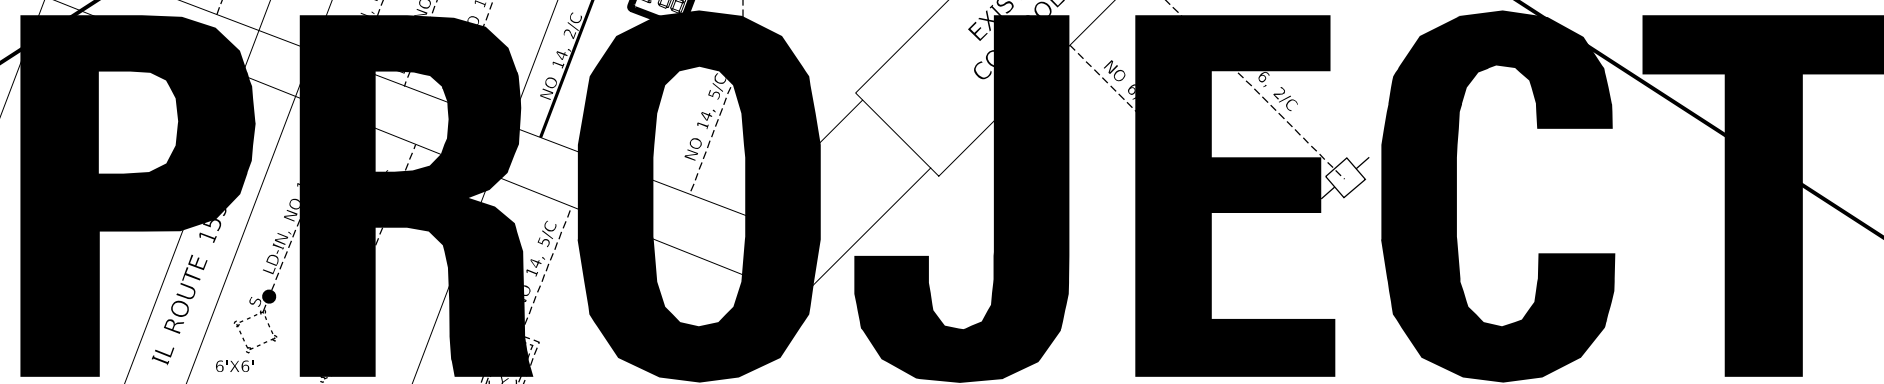

PROJECT

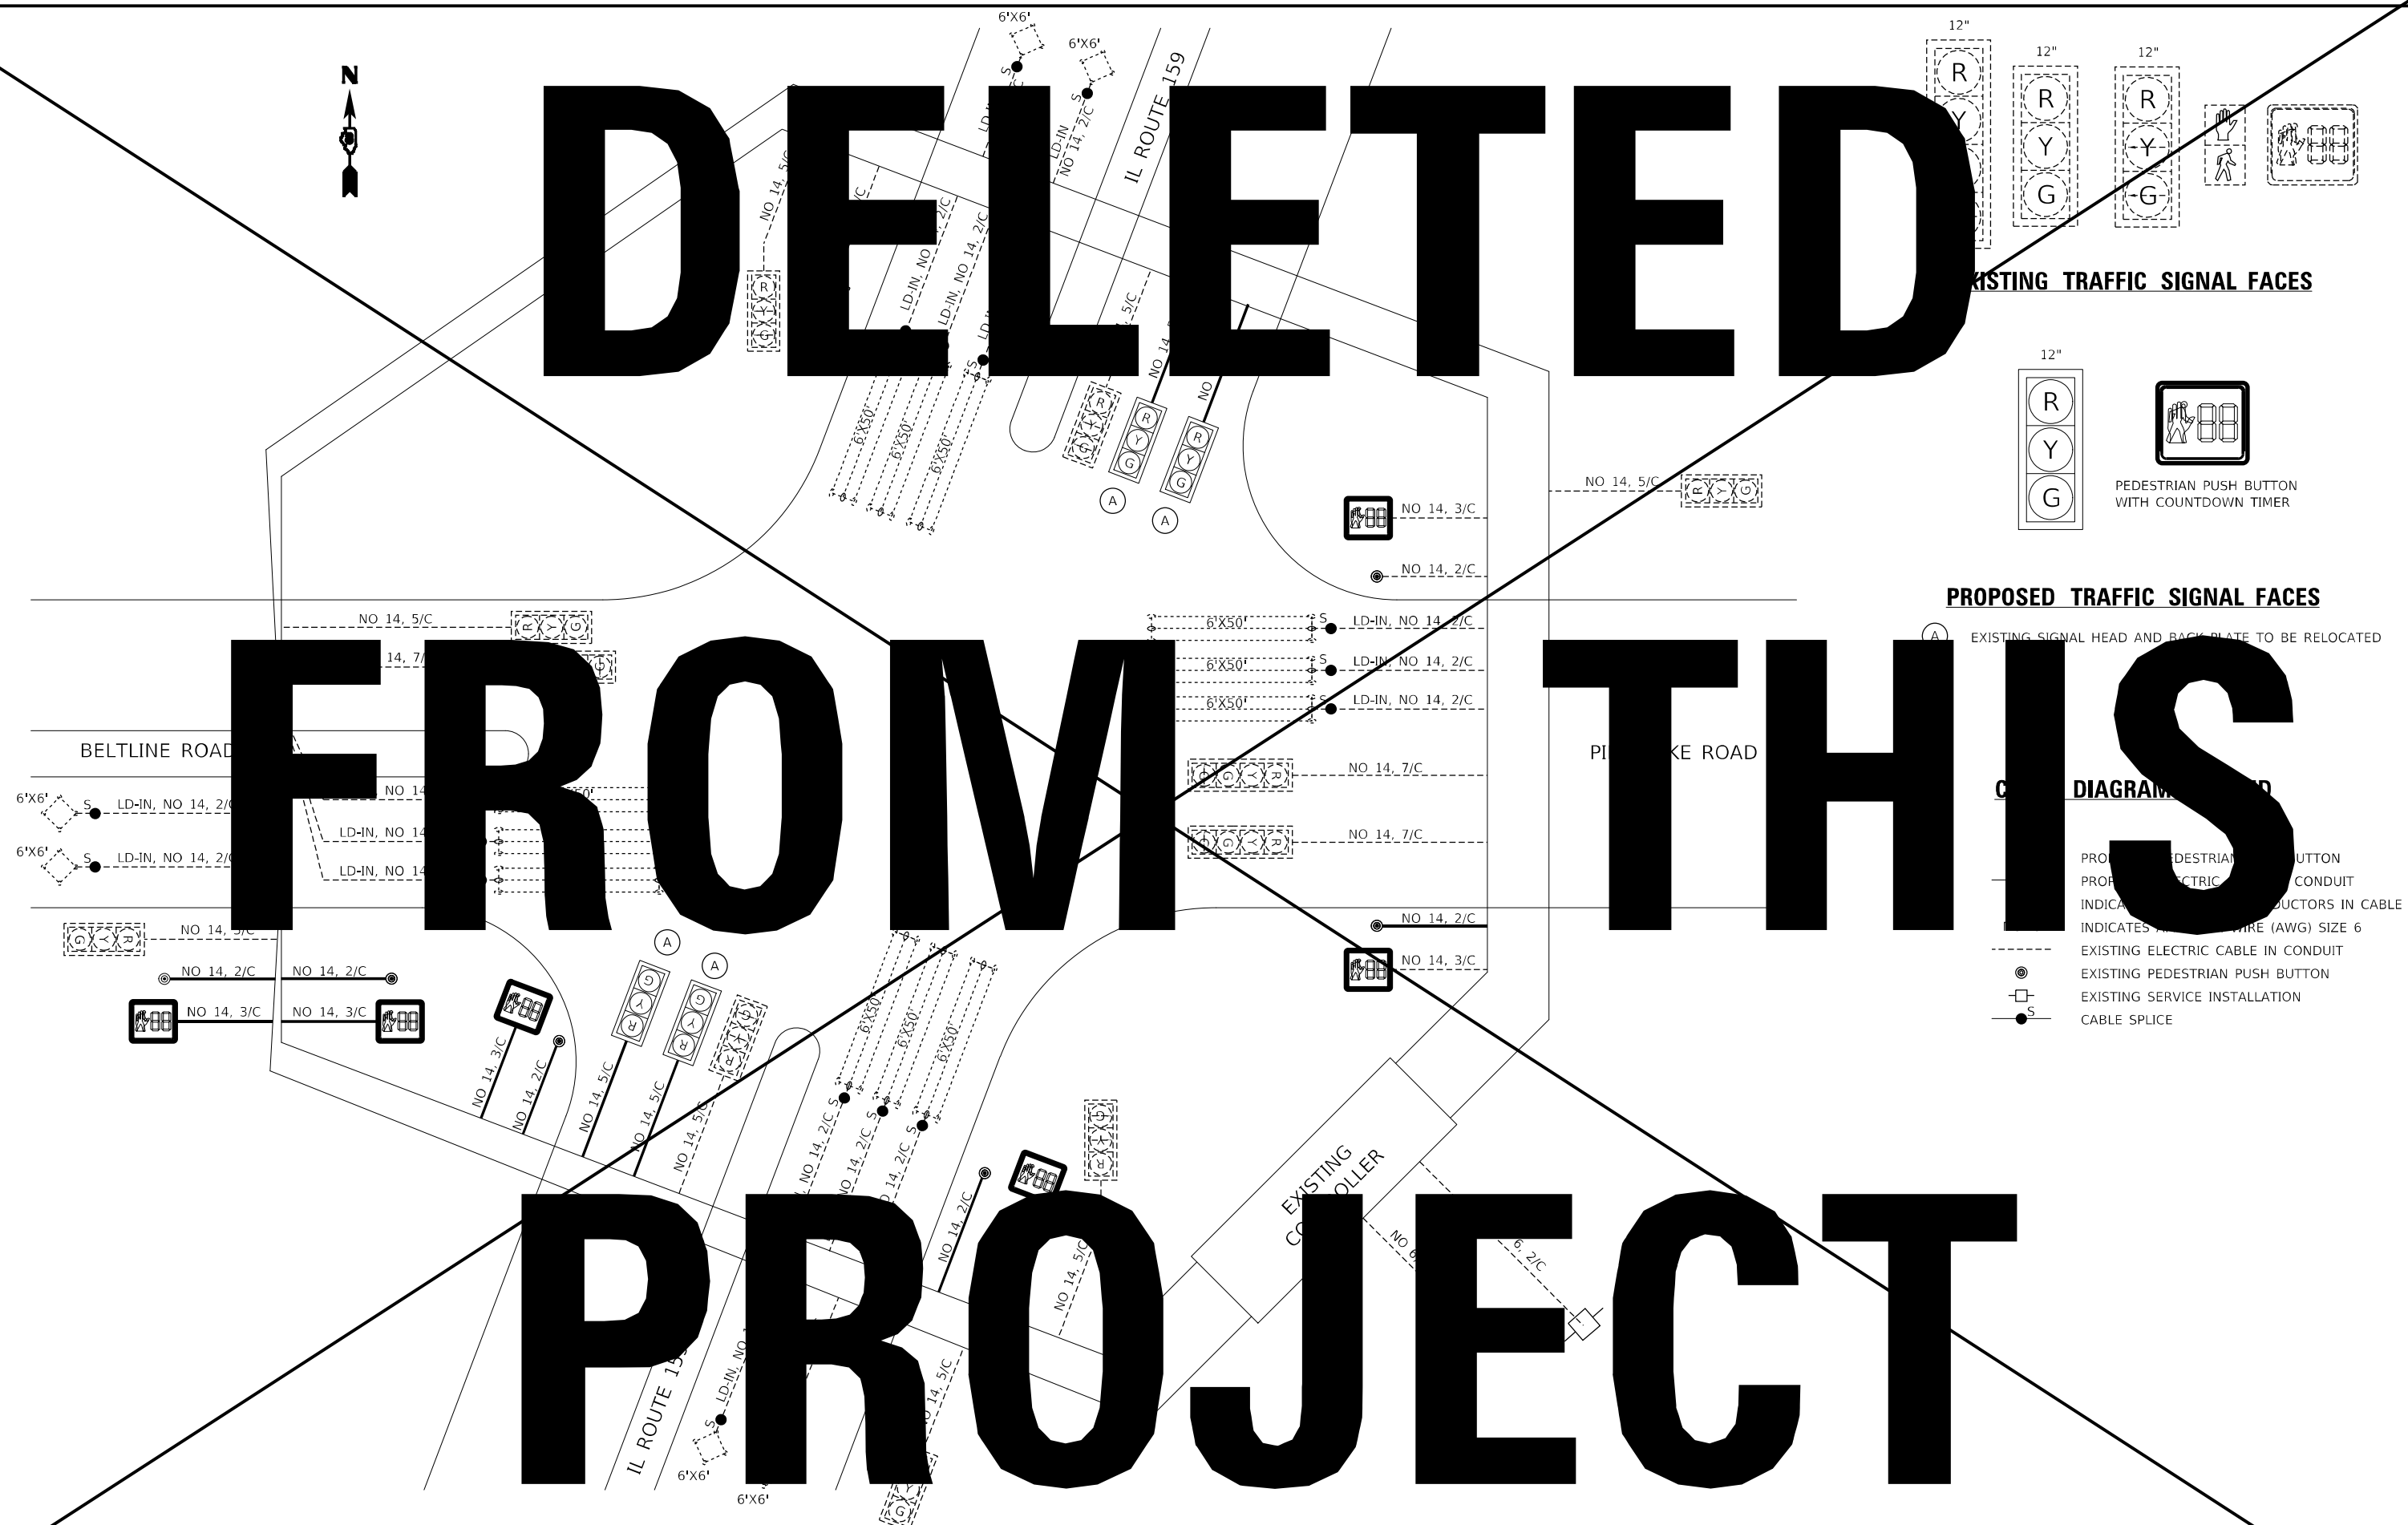

HMG
ENGINEERS

USER NAME	= Default
PLOT SCALE	= 10.0000 ' / in.
PLOT DATE	= 10/26/2022

DESIGNED	-
DRAWN	-
CHECKED	-
DATE	-

REVISED	-
REVISED	-
REVISED	-
REVISED	-

**STATE OF ILLINOIS
DEPARTMENT OF TRANSPORTATION**

CABLE DIAGRAM
IL ROUTE 159 & BELTLINE ROAD /PINE LAKE ROAD

SCALE: NTS	SHEET TS 17 OF 31 SHEETS	STA.	TO STA.
------------	--------------------------	------	---------

F.A.P. RTE.	SECTION	COUNTY	TOTAL SHEETS	SHEET NO.
600	(122,122-1,30)RS-4	MADISON	328	249
		CONTRACT NO. 76M87		
		ILLINOIS FED. AID PROJECT		

ILLINOIS	FED. AID PROJECT
----------	------------------

INSTALL 2 - ELCBL C SIGNAL 14 5C
 INSTALL 2 - ELCBL C SIGNAL 14 2C
 INSTALL 4 - ELCBL C SIGNAL 14 5C
 MOD EX CONC HP
 UC PVC 1.5"
 INSTALL 1 - ELCBL C SIGNAL 14 2C
 INSTALL 1 - ELCBL C EGRDC 6 1C
 CENTER SIGNAL FACE OVER CENTER OF LANE
 IL ROUTE 159
 INSTALL 1 - ELCBL C SIGNAL 14 2C
 UC PVC 1.5"
 INSTALL 1 - ELCBL C SIGNAL 14 2C
 INSTALL 1 - ELCBL C EGRDC 6 1C
 REM ELCBL FR CON
 INSTALL 2 - ELCBL C SIGNAL 14 5C
 CENTER SIGNAL FACE OVER CENTER OF LANE
 IL ROUTE 159

DELETE FROM THIS PROJECT



MODEL: S:\MODEL NAMES
FILE NAME: sru\Alldot-raw_bentley.com\BV\INDOT Documents\INDOT_Offices\District_8\Projects\0876M8VCADData\CADSupport\M8-spl-TS_pln.dgn

HMG
ENGINEERS

IL PROF DESIGN FIRM 184.000899

USER NAME	= Default
PLOT SCALE	= 20,0000'
PLOT DATE	= 10/26/202

DESIGNED	-
DRAWN	-
CHECKED	-
DATE	-

REVISED	-
REVISED	-
REVISED	-
REVISED	-

**STATE OF ILLINOIS
DEPARTMENT OF TRANSPORTATION**

TRAFFIC SIGNAL PLANS

IL ROUTE 159 & CAMELOT DRIVE


SCALE: 1" = 10'	SHEET TS 3 OF 31 SHEETS	STA.	TO STA.
-----------------	-------------------------	------	---------

F.A.P. RTE.	SECTION	COUNTY	TOTAL SHEETS	SHEET NO.
600	(122,122-1,30)RS-4	MADISON	228	250
		CONTRACT NO. 46M87		
ILLINOIS		FED. AID PROJECT		

ILLINOIS	FED. AID PROJECT
----------	------------------

DELETED

EXISTING TRAFFIC SIGNAL FACES

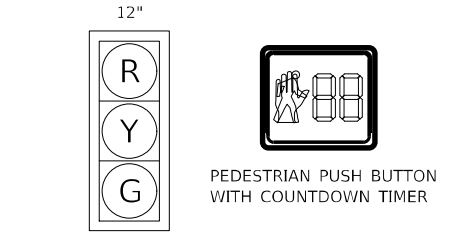

FROM

TO THIS

PROJECT

PROPOSED TRAFFIC SIGNAL FACES

EXISTING SIGNAL HEAD AND BACK PLATE RELOCATED

CABLE DIAGRAM LEGEND

- PROPOSED PEDESTRIAN PUSH BUTTON
- PROPOSED CABLE IN CONDUIT
- 2/C INDICATES NUMBER OF CONDUCTORS IN CABLE
- NO. 6 INDICATES AMERICAN WIRE (AWG) SIZE 6
- EXISTING ELECTRIC CABLE IN CONDUIT
- EXISTING PEDESTRIAN PUSH BUTTON
- EXISTING SERVICE INSTALLATION
- S CABLE SPLICE

STATE OF ILLINOIS
DEPARTMENT OF TRANSPORTATION

CABLE DIAGRAM
IL ROUTE 159 & CAMELOT DRIVE


SCALE: NTS SHEET TS 18 OF 31 SHEETS STA. TO STA.

F.A.P. RTE.	SECTION	COUNTY	TOTAL SHEETS	SHEET NO.
600	(122,122-1,30)RS-4	MADISON	328	251
CONTRACT NO. 76M87				
ILLINOIS FED. AID PROJECT				


HMG
ENGINEERS
IL PROF DESIGN FIRM 184,000899

USER NAME = Default	DESIGNED -	REVISED -
PLOT SCALE = 10,000' / in.	DRAWN -	REVISED -
PLOT DATE = 10/26/2022	CHECKED -	REVISED -
	DATE -	REVISED -


MODEL: \\V:\DOT\Documents\DOT Office\Director_8\Projects\0876487\CADDData\CADD\Sheet\HMG\2022-10-26\0876487-sh-25 Scale Diagrams.dgn
FILE: \\V:\DOT\Documents\DOT Office\Director_8\Projects\0876487\CADDData\CADD\Sheet\HMG\2022-10-26\0876487-sh-25 Scale Diagrams.dgn

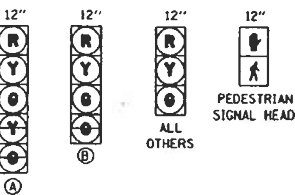

PROPOSED TRAFFIC SIGNAL FACES

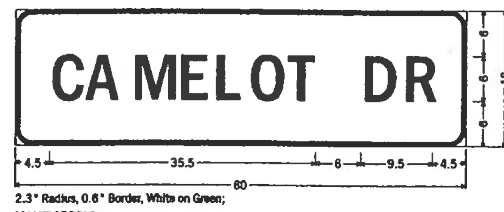


STREET NAME SIGN
DETAIL C
NOT TO SCALE

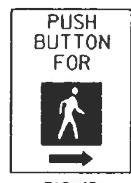


R10-4B
9 x 12

DETAIL D
NOT TO SCALE

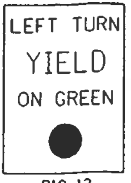

R10-12
24 x 30

DETAIL E
NOT TO SCALE

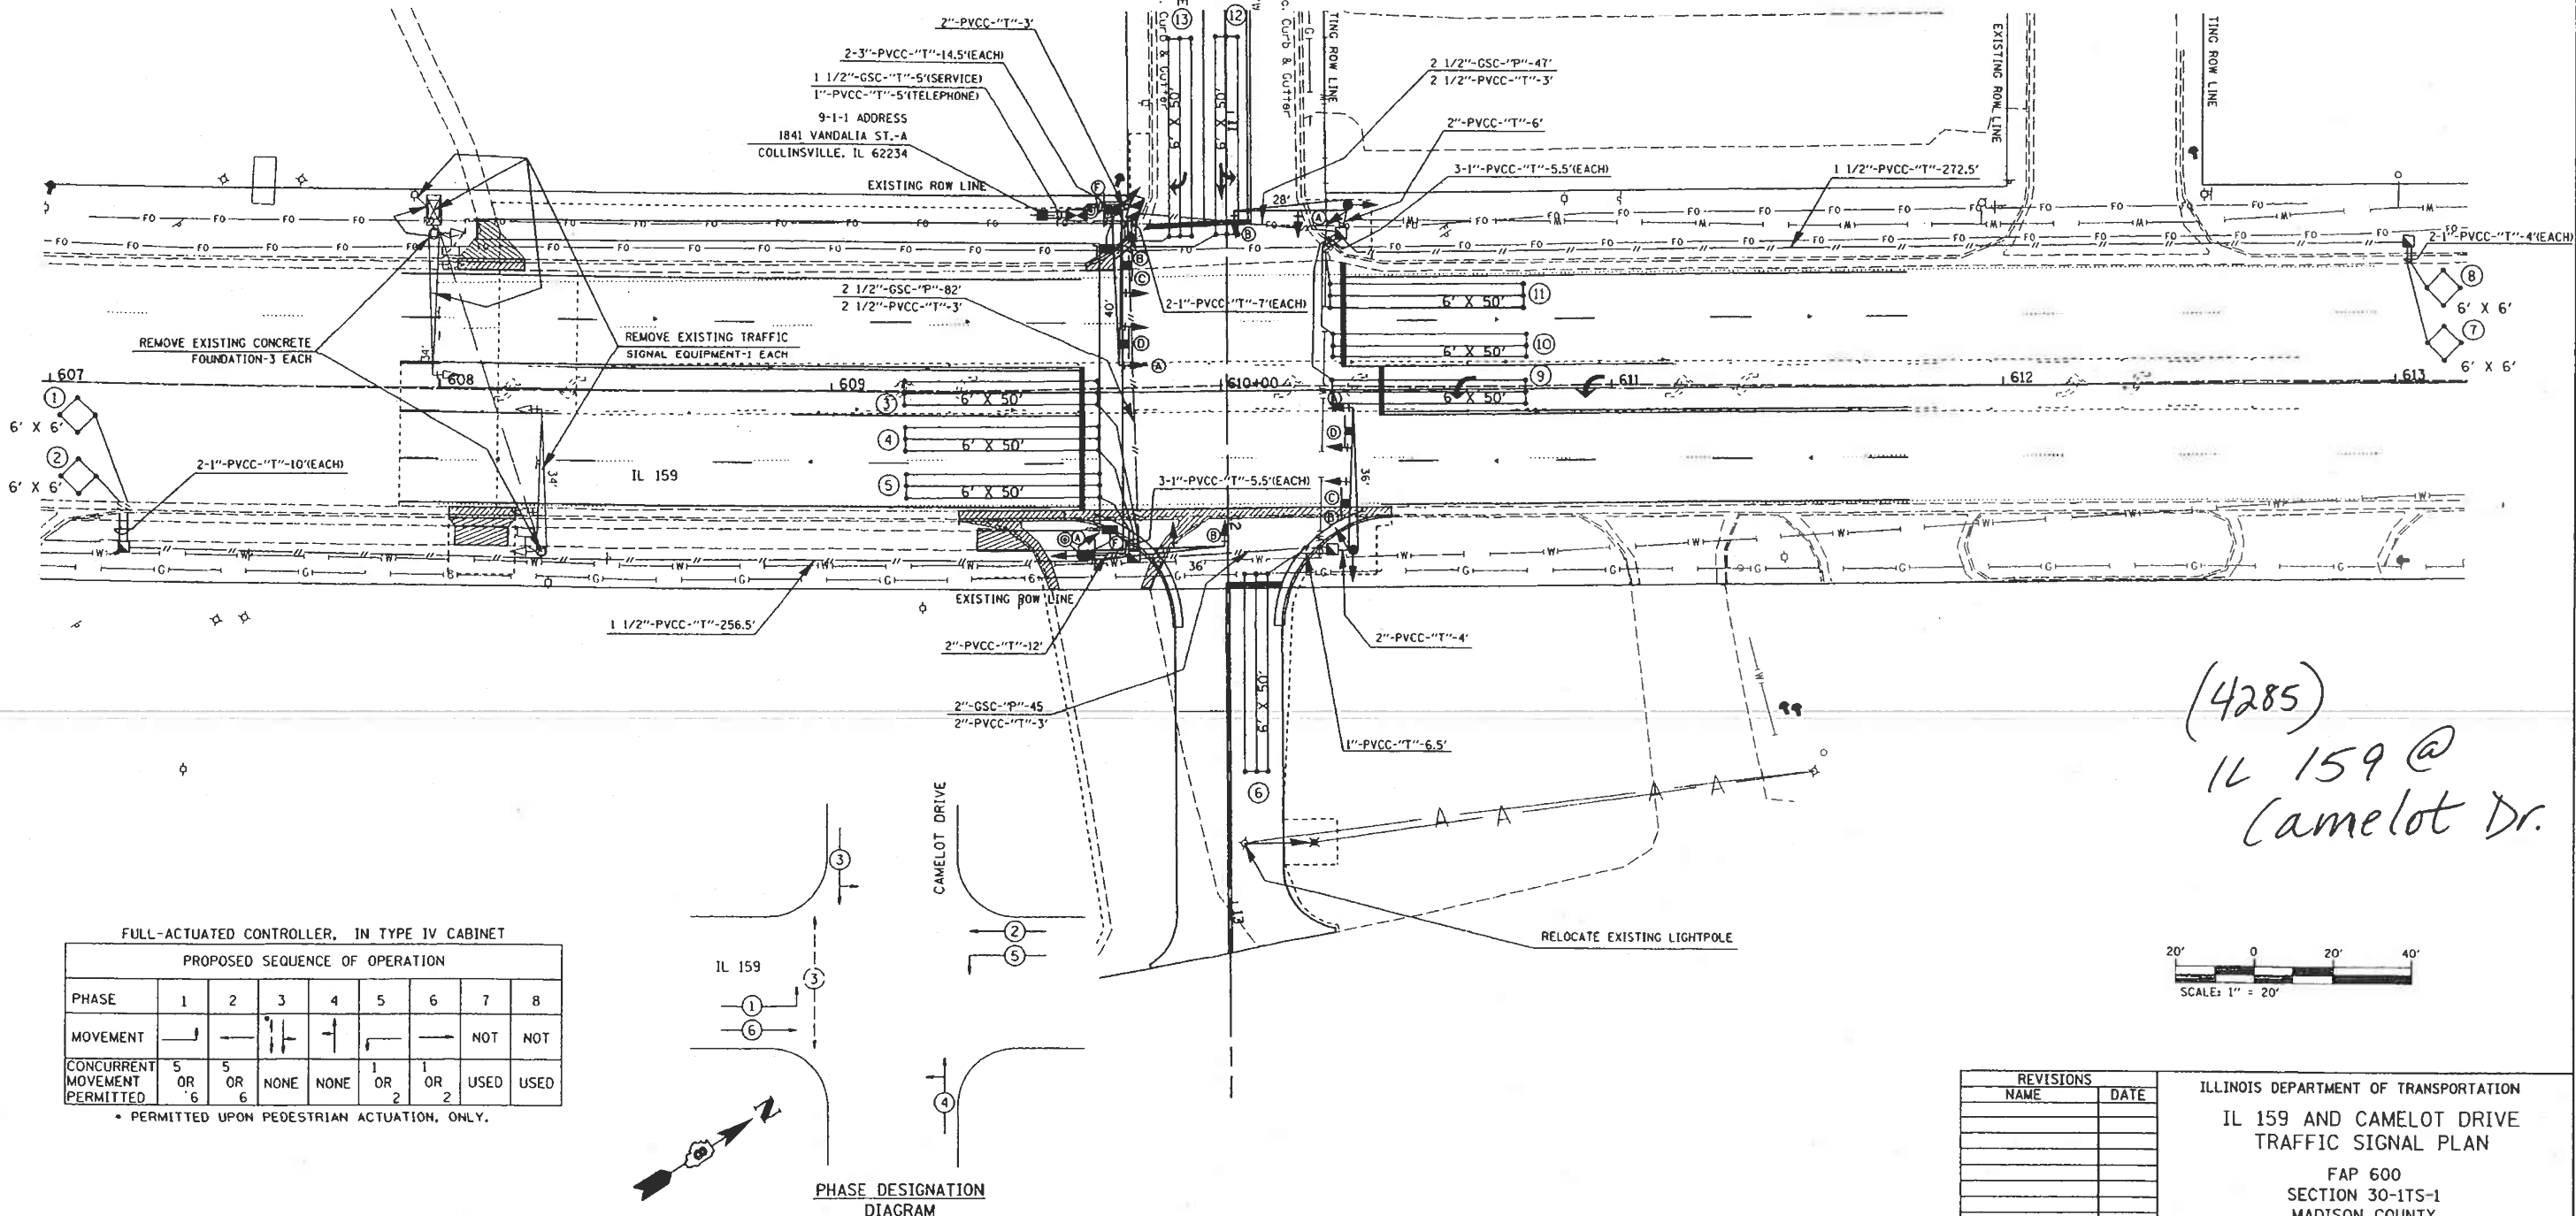


(4285)
IL 159 @
Camelot Dr.

FULL-ACTUATED CONTROLLER, IN TYPE IV CABINET

PROPOSED SEQUENCE OF OPERATION								
PHASE	1	2	3	4	5	6	7	8
MOVEMENT	—	—	—	—	—	—	NOT	NOT
CONCURRENT MOVEMENT PERMITTED	5 OR 6	5 OR 6	NONE	NONE	1 OR 2	1 OR 2	USED	USED

• PERMITTED UPON PEDESTRIAN ACTUATION, ONLY.

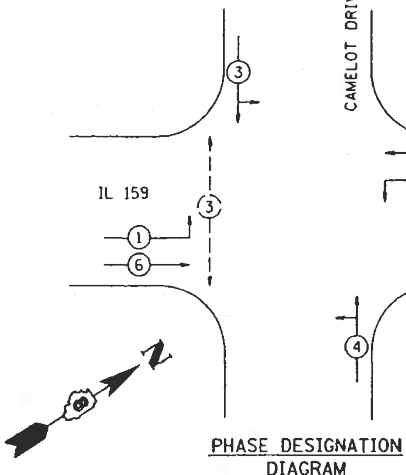

REVISIONS	
NAME	DATE

ILLINOIS DEPARTMENT OF TRANSPORTATION
IL 159 AND CAMELOT DRIVE
TRAFFIC SIGNAL PLAN
FAP 600
SECTION 30-ITS-1
MADISON COUNTY
SCALE: VERT. 1" = 20'
HORIZ. 1" = 40'
DATE: DRAWN BY: CHECKED BY:

MODEL: Default
FILE NAME: 103066_10DOT.DWG
PLOT: 103066_10DOT.DWG
PLOT DATE: 6/30/2022

HMG
ENGINEERS
IL PROF DESIGN FIRM 184,000899

USER NAME	= nseelhoefer	DESIGNED	-	REVISED	-
PLOT SCALE	= 0.1667" / in.	DRAWN	-	REVISED	-
PLOT DATE	= 6/30/2022	CHECKED	-	REVISED	-
		DATE	-	REVISED	-


STATE OF ILLINOIS
DEPARTMENT OF TRANSPORTATION

AS BUILT
IL ROUTE 159 & CAMELOT DRIVE

SCALE: SHEET OF SHEETS STA. TO STA.

FAU RTE	SECTION	COUNTY	TOTAL SHEETS	SHEET NO.
8887	(122,122-1,30)RS-4	MADISON	328	251A
CONTRACT NO. 76M87				
ILLINOIS FED. AID PROJECT				

MODEL: \\MODELS\\MAMES
FILE NAME: \\models\\mames\\bentley.com\\P\\IDOT\\Documents\\IDOT - Offices\\District 8\\Projects\\D876M87\\CADD\\Data\\CAD\\streets\\HMC\\2022-10-24\\D876M87-sht-TS Pln.dgn


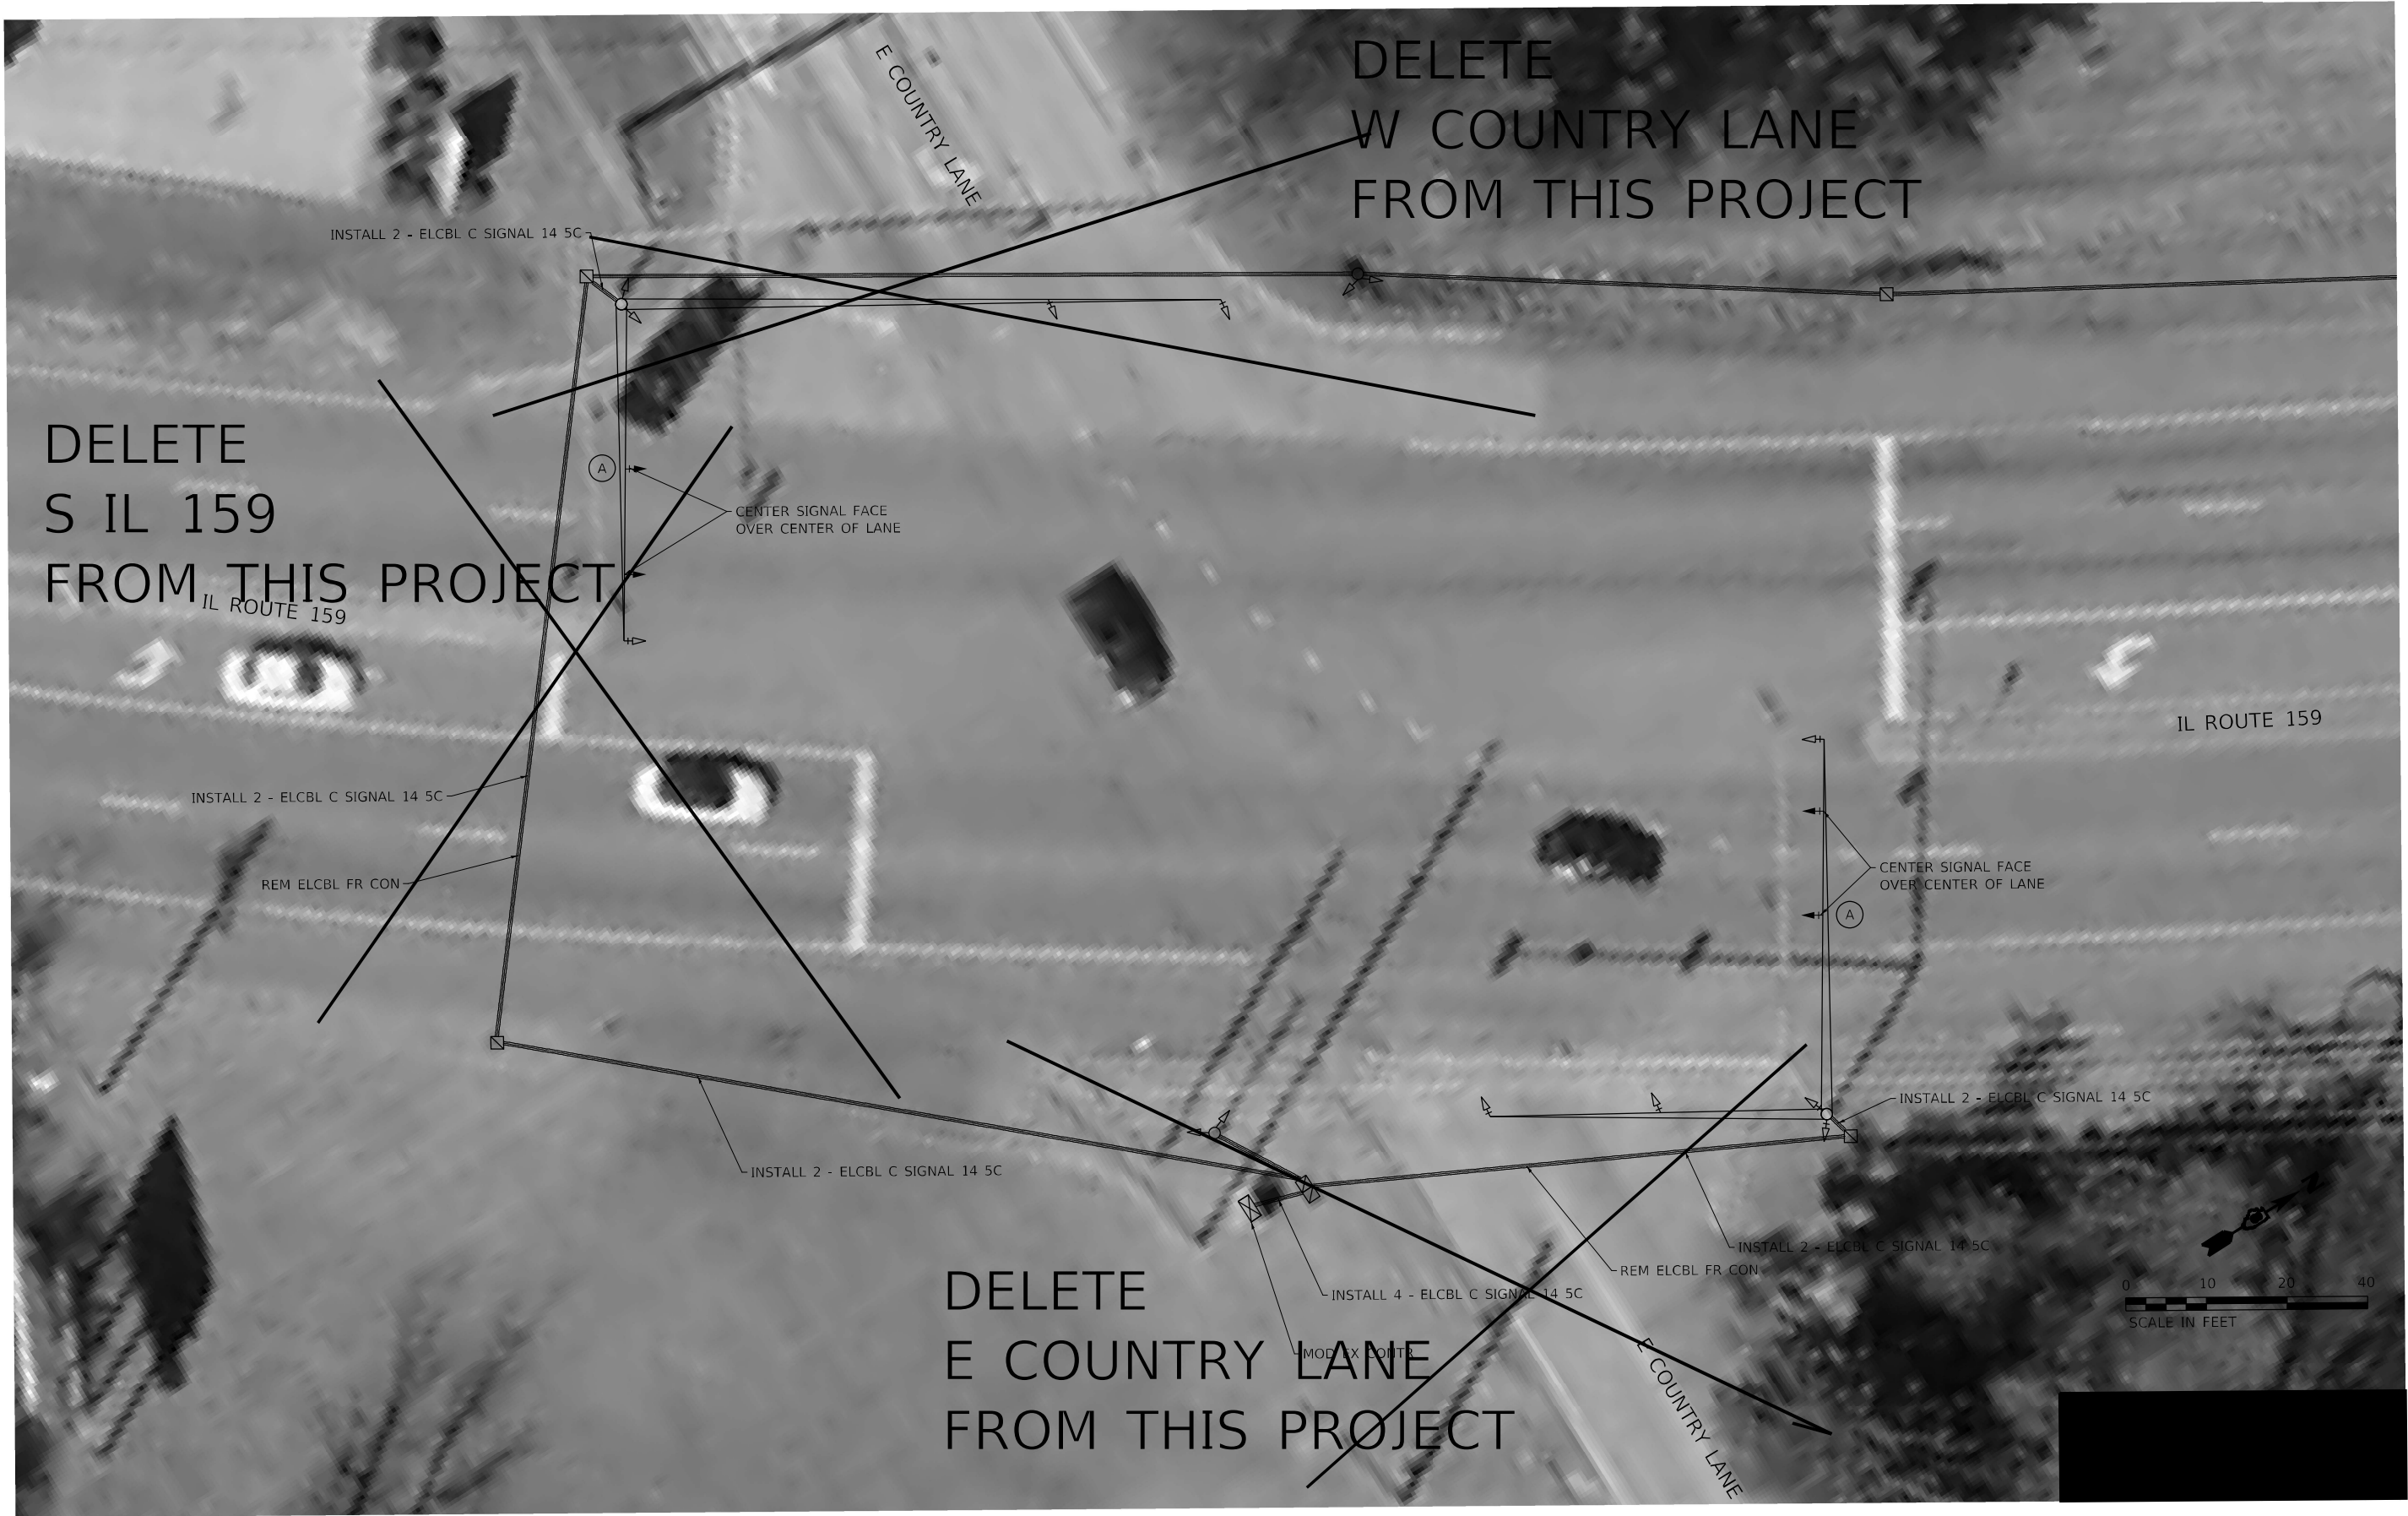


USER NAME	= Default	DESIGNED	-	REVISED	-	AMM-102622
DRAWN	-	CHECKED	-	REVISD	-	
PLOT SCALE	= 20.1005' / in.	DATE	-	REVISD	-	
PLOT DATE	= 10/26/2022					


STATE OF ILLINOIS DEPARTMENT OF TRANSPORTATION

TRAFFIC SIGNAL PLANS IL ROUTE 159 & E COUNTRY LANE			
SCALE: 1" = 10'	SHEET TS 4 OF 31 SHEETS	STA.	TO STA.

F.A.P. RTE.	SECTION	COUNTY	TOTAL SHEETS	SHEET NO.
600	(122,122-1.30)RS-4	MADISON	328	252
CONTRACT NO. 76M87				
ILLINOIS FED. AID PROJECT				

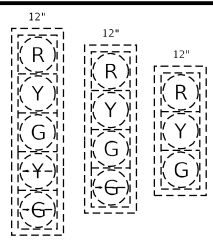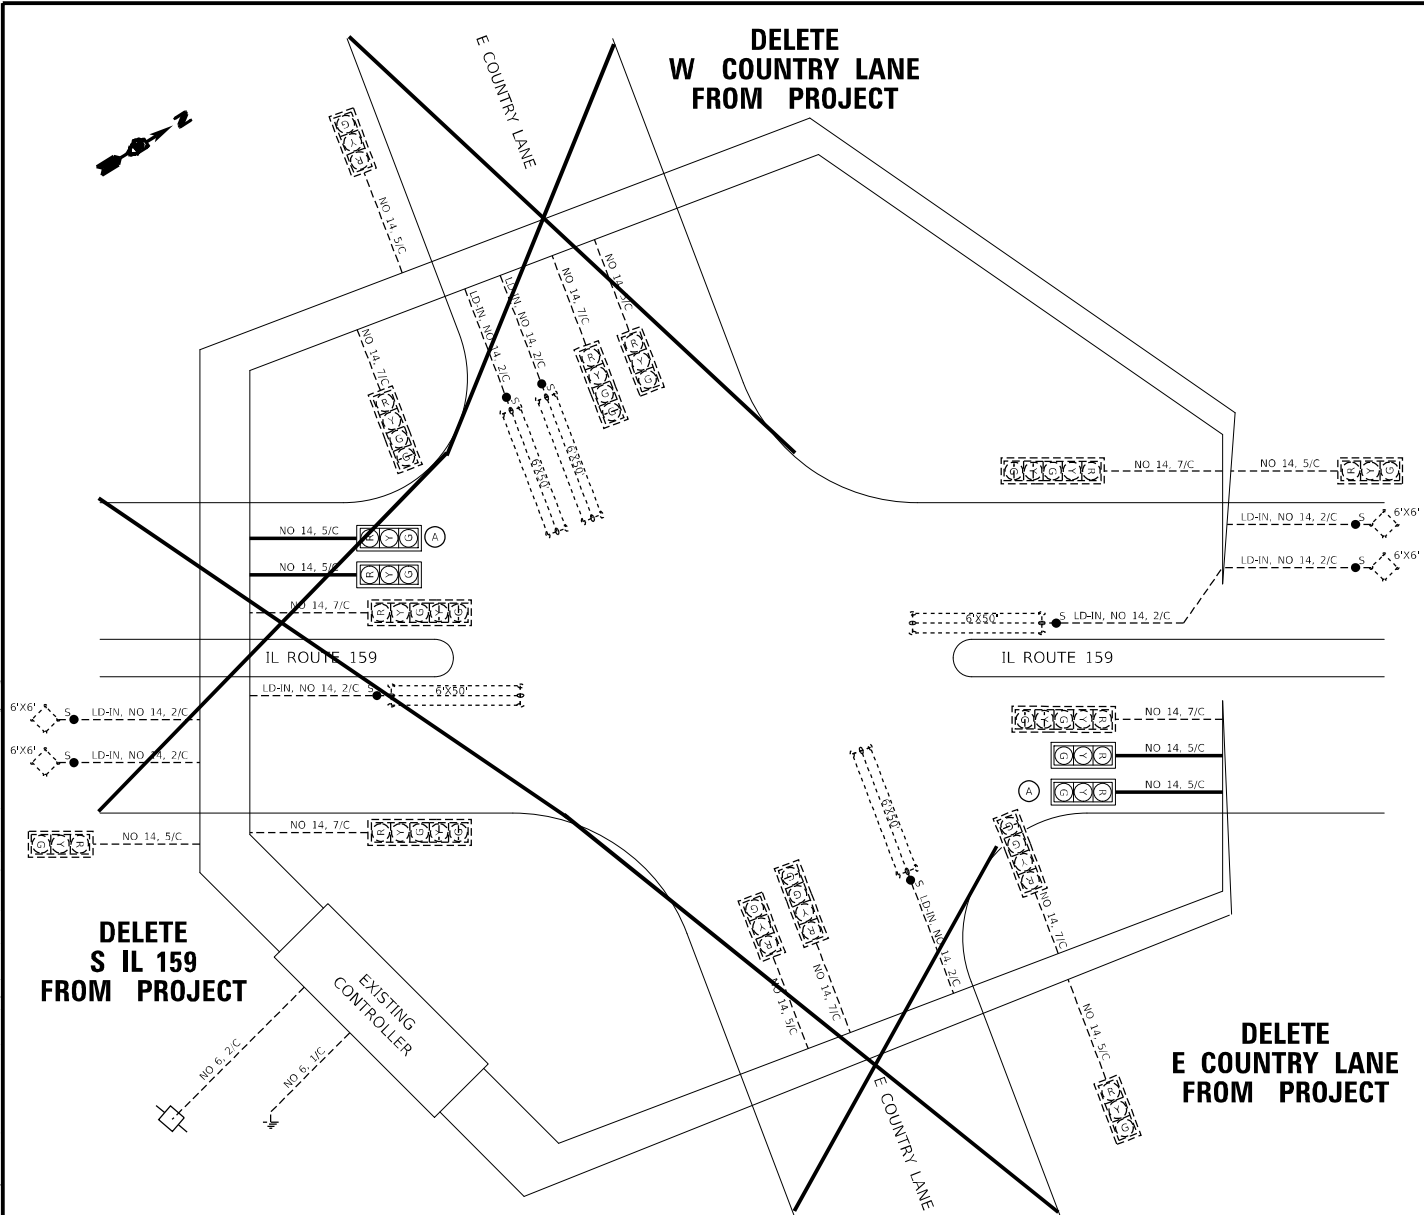

EXISTING TRAFFIC SIGNAL FACES

 


PROPOSED TRAFFIC SIGNAL FACES

(A) EXISTING SIGNAL HEAD AND BACK PLATE TO BE RELOCATED

CABLE DIAGRAM LEGEND

- PROPOSED ELECTRIC CABLE IN CONDUIT
- 2/C INDICATES NUMBER OF CONDUCTORS IN CABLE
- NO. 6 INDICATES AMERICAN WIRE (AWG) SIZE 6
- EXISTING ELECTRIC CABLE IN CONDUIT
- EXISTING PEDESTRIAN PUSH BUTTON
- EXISTING SERVICE INSTALLATION
- CABLE SPLICE

PROJECT: 159 & COUNTRY LANE FILE: 159-102622-001	USER NAME = Dario B.		DESIGNED =	REVISED = AMH-10/2022	STATE OF ILLINOIS DEPARTMENT OF TRANSPORTATION	CABLE DIAGRAM IL ROUTE 159 & E COUNTRY LANE	P&E SHEET 600	SECTION (122.122-1.30/RS-4)	COUNTY MADISON	TOTAL SHEETS 328	SHEET NO. 255	CONTRACT NO. 76M87	
			DRAWN =	REVISED =									
	PLOT SCALE = 15.4345" = 1'		CHECKED =	REVISED =									
	PLOT DATE = 10/26/2022		DATE =	REVISED =									
SCALE: NTS						SHEET TS 19 OF 31		SHEETS STA.		TO STA.		ILLINOIS DEPT. OF TRANSPORTATION	

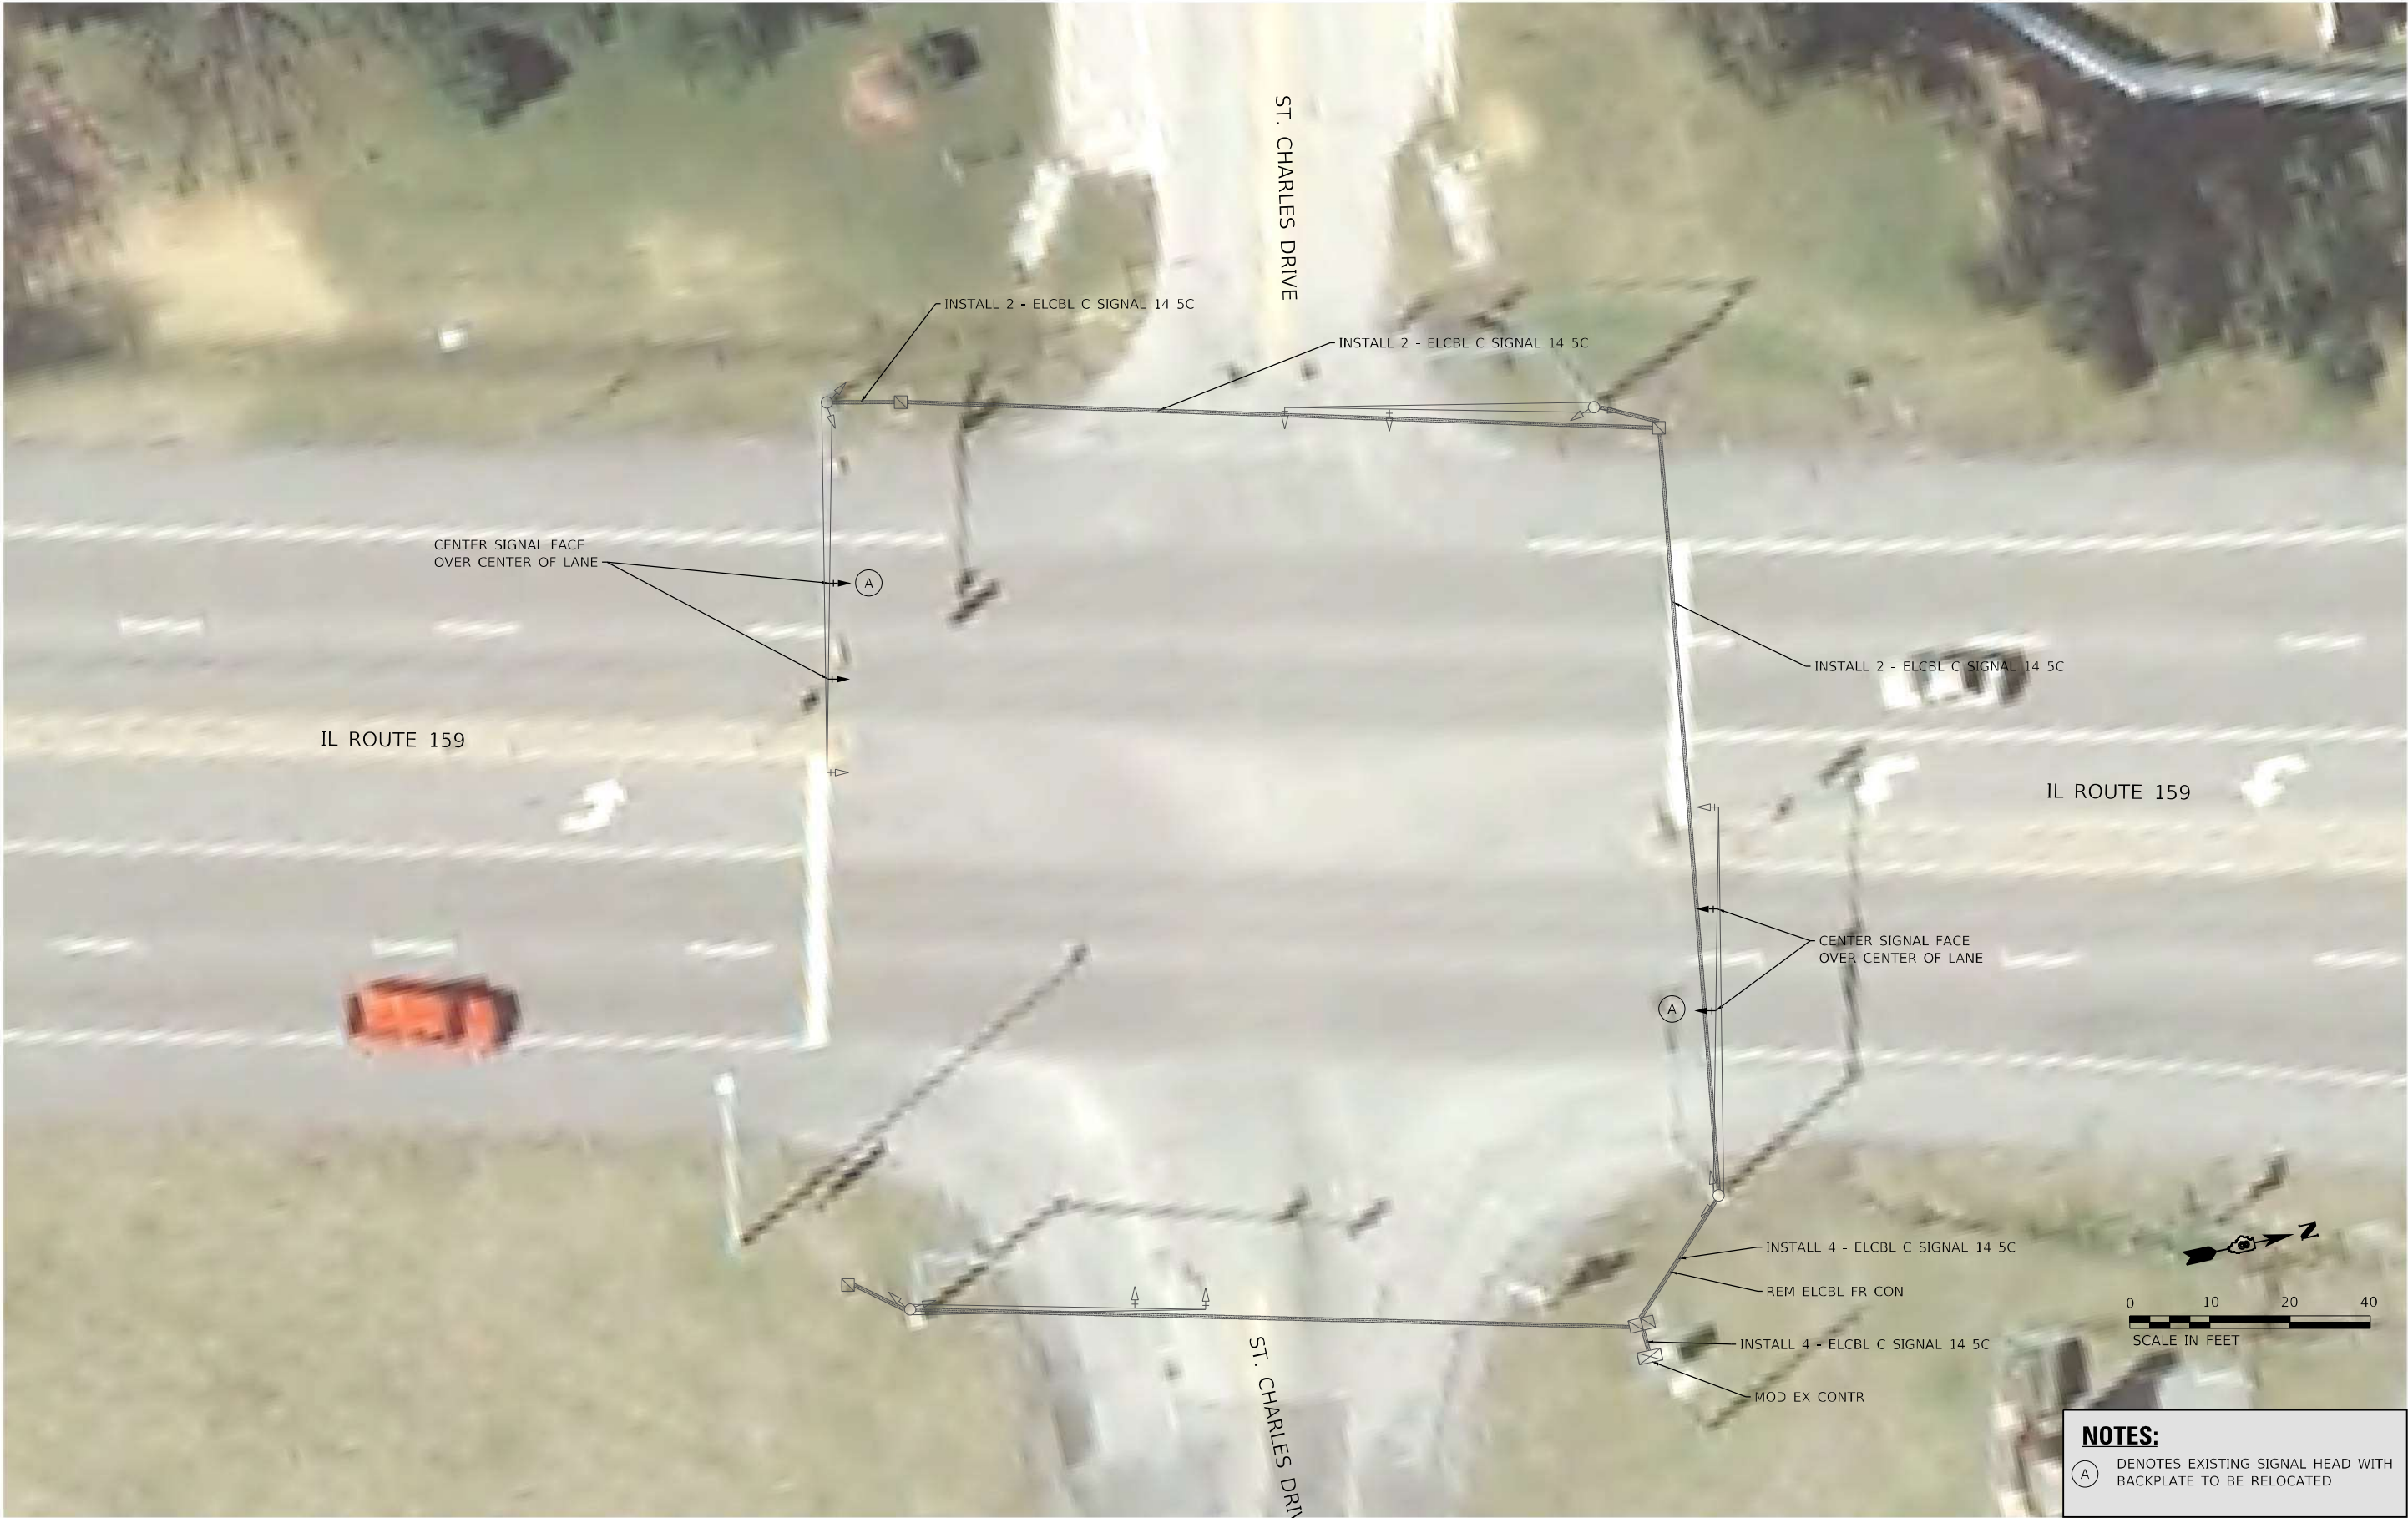

NOTES:
(A) DENOTES EXISTING SIGNAL HEAD WITH BACKPLATE TO BE RELOCATED

MODEL: Sheet 5 - St. Charles
FILE NAME: 108249_05_139_0218249_010_W01_IL159_Traffic_Signal_Upgrade\Card_Sheets\0876M87.dgn

HMG
ENGINEERS
IL PROF DESIGN FIRM 184,000899

USER NAME	= nseelhoefer	DESIGNED	-	REVISED	-
DRAWN	-	REVISION	-	REVISION	-
PLOT SCALE	= 20,0000 ' / in.	CHECKED	-	REVISION	-
PLOT DATE	= 6/30/2022	DATE	-	REVISION	-

STATE OF ILLINOIS
DEPARTMENT OF TRANSPORTATION

TRAFFIC SIGNAL PLANS			
IL ROUTE 159 & ST. CHARLES DRIVE			
SCALE: 1" = 10'	SHEET TS 5 OF 31 SHEETS	STA.	TO STA.

F.A.P. RTE.	SECTION	COUNTY	TOTAL SHEETS	SHEET NO.
600	(122,122-1,30)RS-4	MADISON	328	254
CONTRACT NO. 76M87				
ILLINOIS FED. AID PROJECT				

MODEL: Sheet 20 - St. Charles
FILE NAME: 188249_010_199_0218249_010_W01_IL159_Traffic_Signal_Upgrade\Card_Sheets\0876M87-Cable_Diagram.dgn



USER NAME	= nseelhoefer
PLOT SCALE	= 10,0000 ' / in.
PLOT DATE	= 6/30/2022



DESIGNED -	
DRAWN -	
CHECKED -	
DATE -	

REVISED -	
REVISED -	
REVISED -	
REVISED -	


STATE OF ILLINOIS
DEPARTMENT OF TRANSPORTATION

CABLE DIAGRAM IL ROUTE 159 & ST. CHARLES DRIVE			
SCALE: NTS	SHEET TS 20 OF 31 SHEETS	STA.	TO STA.

F.A.P. RTE.	SECTION	COUNTY	TOTAL SHEETS	SHEET NO.
600	(122,122-1,30)RS-4	MADISON	328	255
CONTRACT NO. 76M87				
ILLINOIS FED. AID PROJECT				

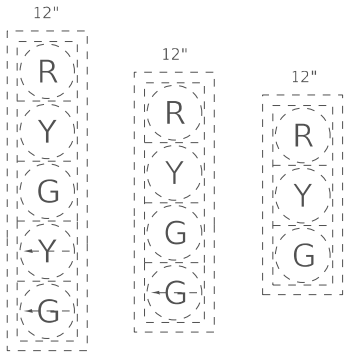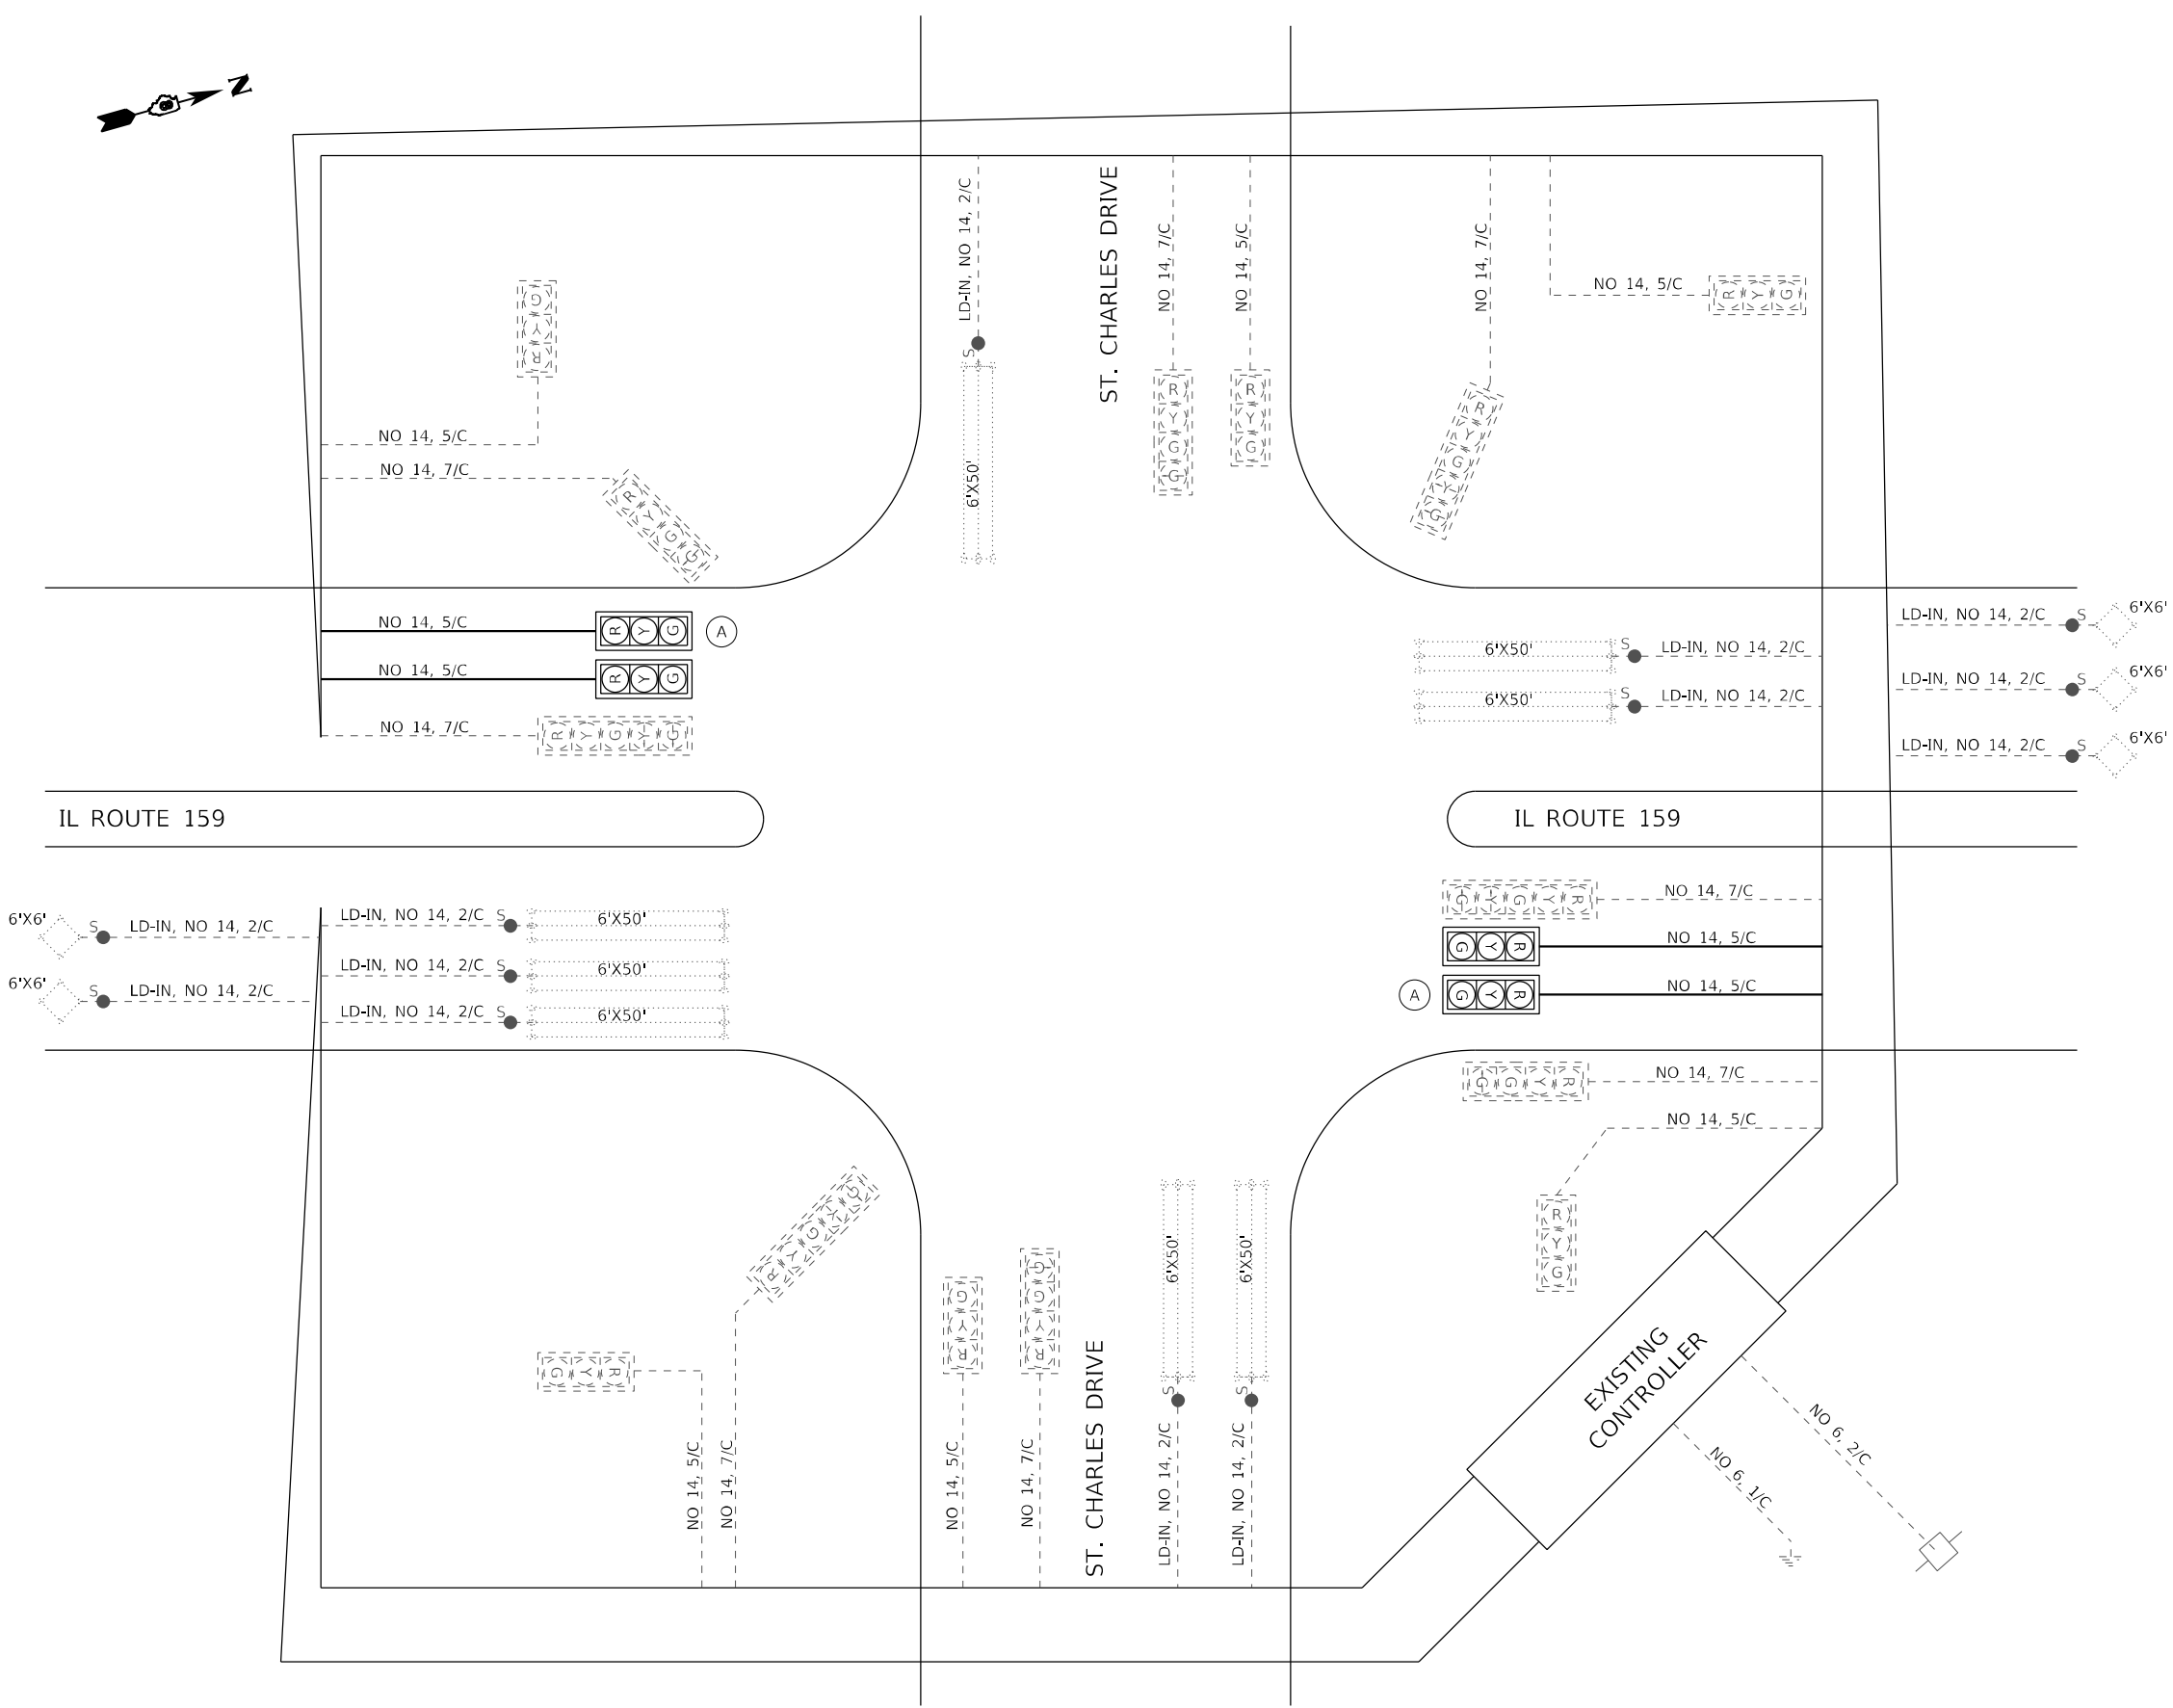

EXISTING TRAFFIC SIGNAL FACES

 

PROPOSED TRAFFIC SIGNAL FACES

A EXISTING SIGNAL HEAD AND BACK PLATE TO BE RELOCATED

CABLE DIAGRAM LEGEND

- PROPOSED ELECTRIC CABLE IN CONDUIT
- 2/C INDICATES NUMBER OF CONDUCTORS IN CABLE
- NO. 6 INDICATES AMERICAN WIRE (AWG) SIZE 6
- EXISTING ELECTRIC CABLE IN CONDUIT
- EXISTING PEDESTRIAN PUSH BUTTON
- EXISTING SERVICE INSTALLATION
- CABLE SPLICE

300 300 300


R Y C Y G R Y C G R Y C

(A) (B) ALL OTHERS

LEFT TURN
YIELD
ON GREEN

DETAIL B
NOT TO SCALE

PROPOSED TRAFFIC
SIGNAL FACES

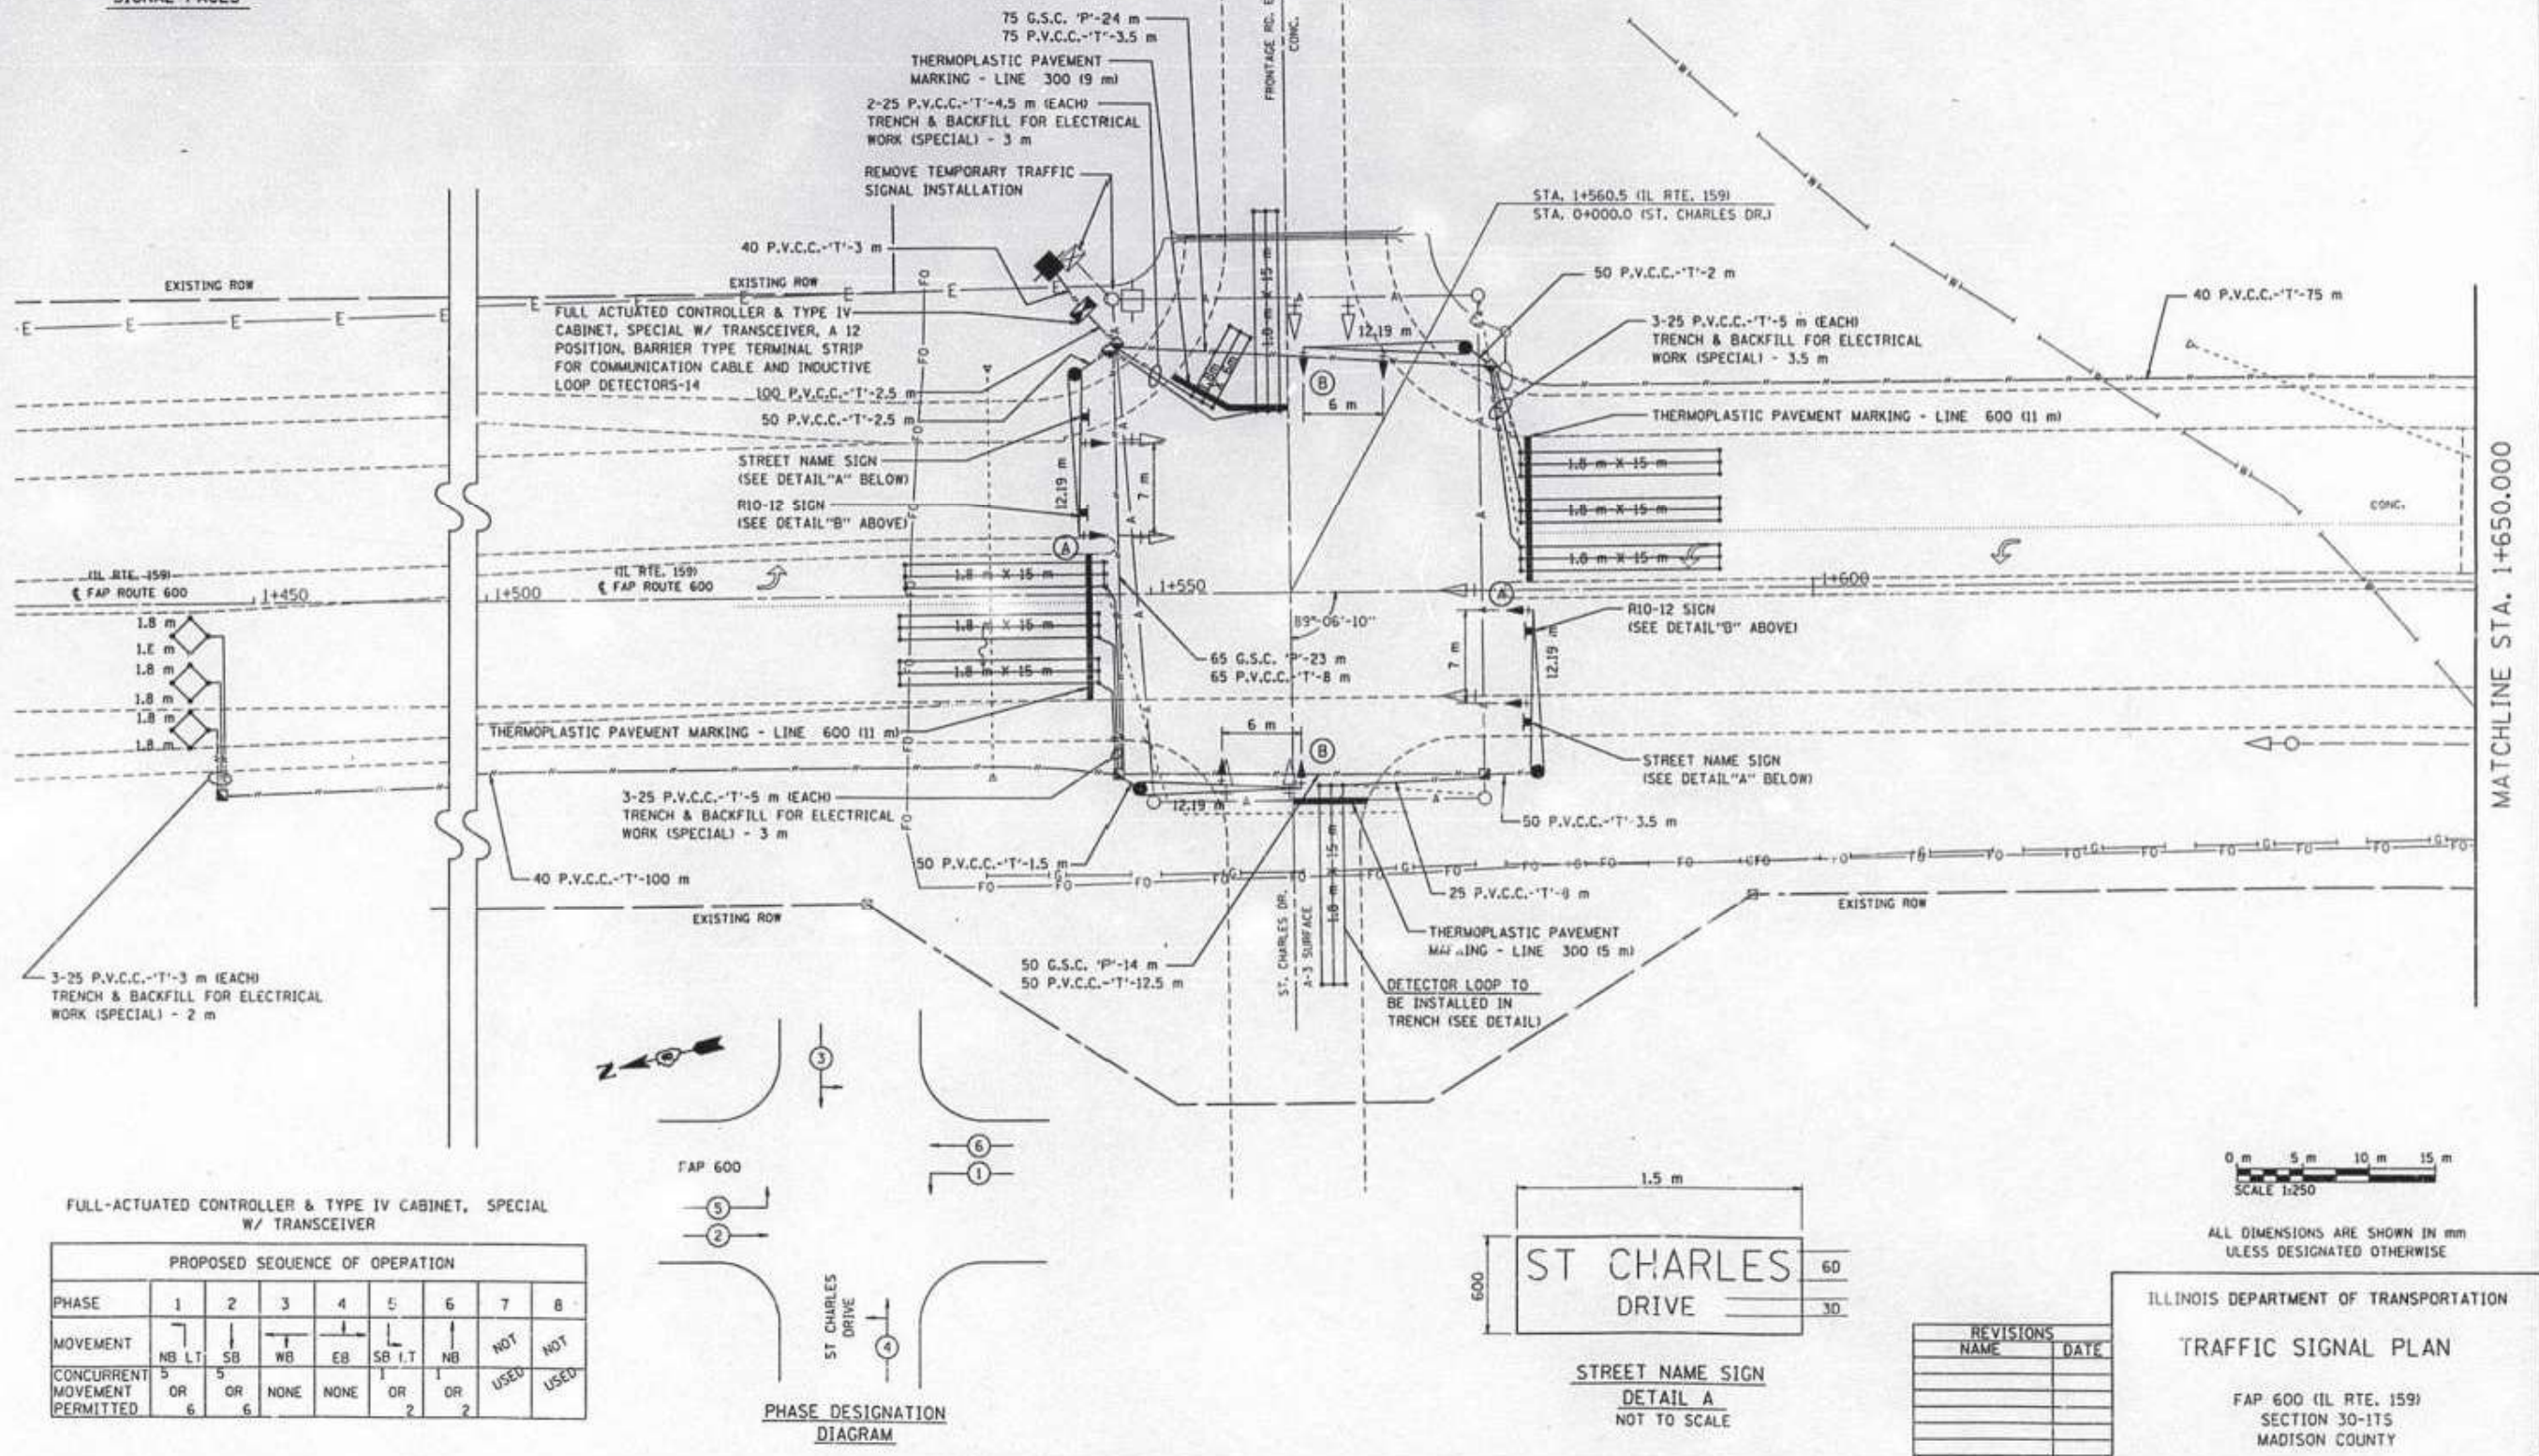

PROPOSED SEQUENCE OF OPERATION								
PHASE	1	2	3	4	5	6	7	8
MOVEMENT	 NB LT	 SB	 WB	 EB	 NB LT	 NB	NOT	NOT
CONCURRENT MOVEMENT PERMITTED	OR 5	OR 6	NONE	NONE	OR 2	OR 2	USED	USED

PHASE DESIGNATION
DIAGRAM

REVISIONS	
NAME	DATE

TRAFFIC SIGNAL PLAN

FAP 600 (IL RTE. 159)
SECTION 30-1TS
MADISON COUNTY



NOTES:
Ⓐ DENOTES EXISTING SIGNAL HEAD WITH BACKPLATE TO BE RELOCATED

MODEL: Sheet 6 - 155-70 N
FILE NAME: 1088249_270_130_02282919_010_W01_IL159_Traffic_Signal_Upgrade.dgn

HMG
ENGINEERS
IL PROF DESIGN FIRM 184,000899

USER NAME = nseelhoefer	DESIGNED -	REVISED -
	DRAWN -	REVISED -
PLOT SCALE = 20,000' / in.	CHECKED -	REVISED -
PLOT DATE = 6/30/2022	DATE -	REVISED -

STATE OF ILLINOIS
DEPARTMENT OF TRANSPORTATION

TRAFFIC SIGNAL PLANS			
IL ROUTE 159 & I-55 / 70 RAMPS NORTH JUNCTION			
SCALE: 1" = 10'	SHEET TS 6 OF 31 SHEETS	STA.	TO STA.

F.A.P. RTE.	SECTION	COUNTY	TOTAL SHEETS	SHEET NO.
600	(122,122-1,30)RS-4	MADISON	328	256
				CONTRACT NO. 76M87
		ILLINOIS	FED. AID PROJECT	

MODEL: Sheet 21 - I-55 Junction
FILE NAME: 188249_210_139_0218249_010.WD1_IL159_Traffic_Signal_Upgrade\Card_Sheets\0876M87-Cable_Diagram.dgn



IL PROF DESIGN FIRM 184,000899

USER NAME	= nseelhoefer
PLOT SCALE	= 10,0000 ' / in.
PLOT DATE	= 6/30/2022

DESIGNED	-
DRAWN	-
CHECKED	-
DATE	-


REVISED	-
REVISED	-
REVISED	-
REVISED	-

STATE OF ILLINOIS
DEPARTMENT OF TRANSPORTATION


CABLE DIAGRAM
IL ROUTE 159 & I-55/70 RAMPS NORTH JUNCTION

SCALE: NTS SHEET TS 21 OF 31 SHEETS STA. TO STA.

F.A.P. RTE.	SECTION	COUNTY	TOTAL SHEETS	SHEET NO.
600	(122,122-1,30)RS-4	MADISON	328	257
CONTRACT NO. 76M87				
ILLINOIS FED. AID PROJECT				

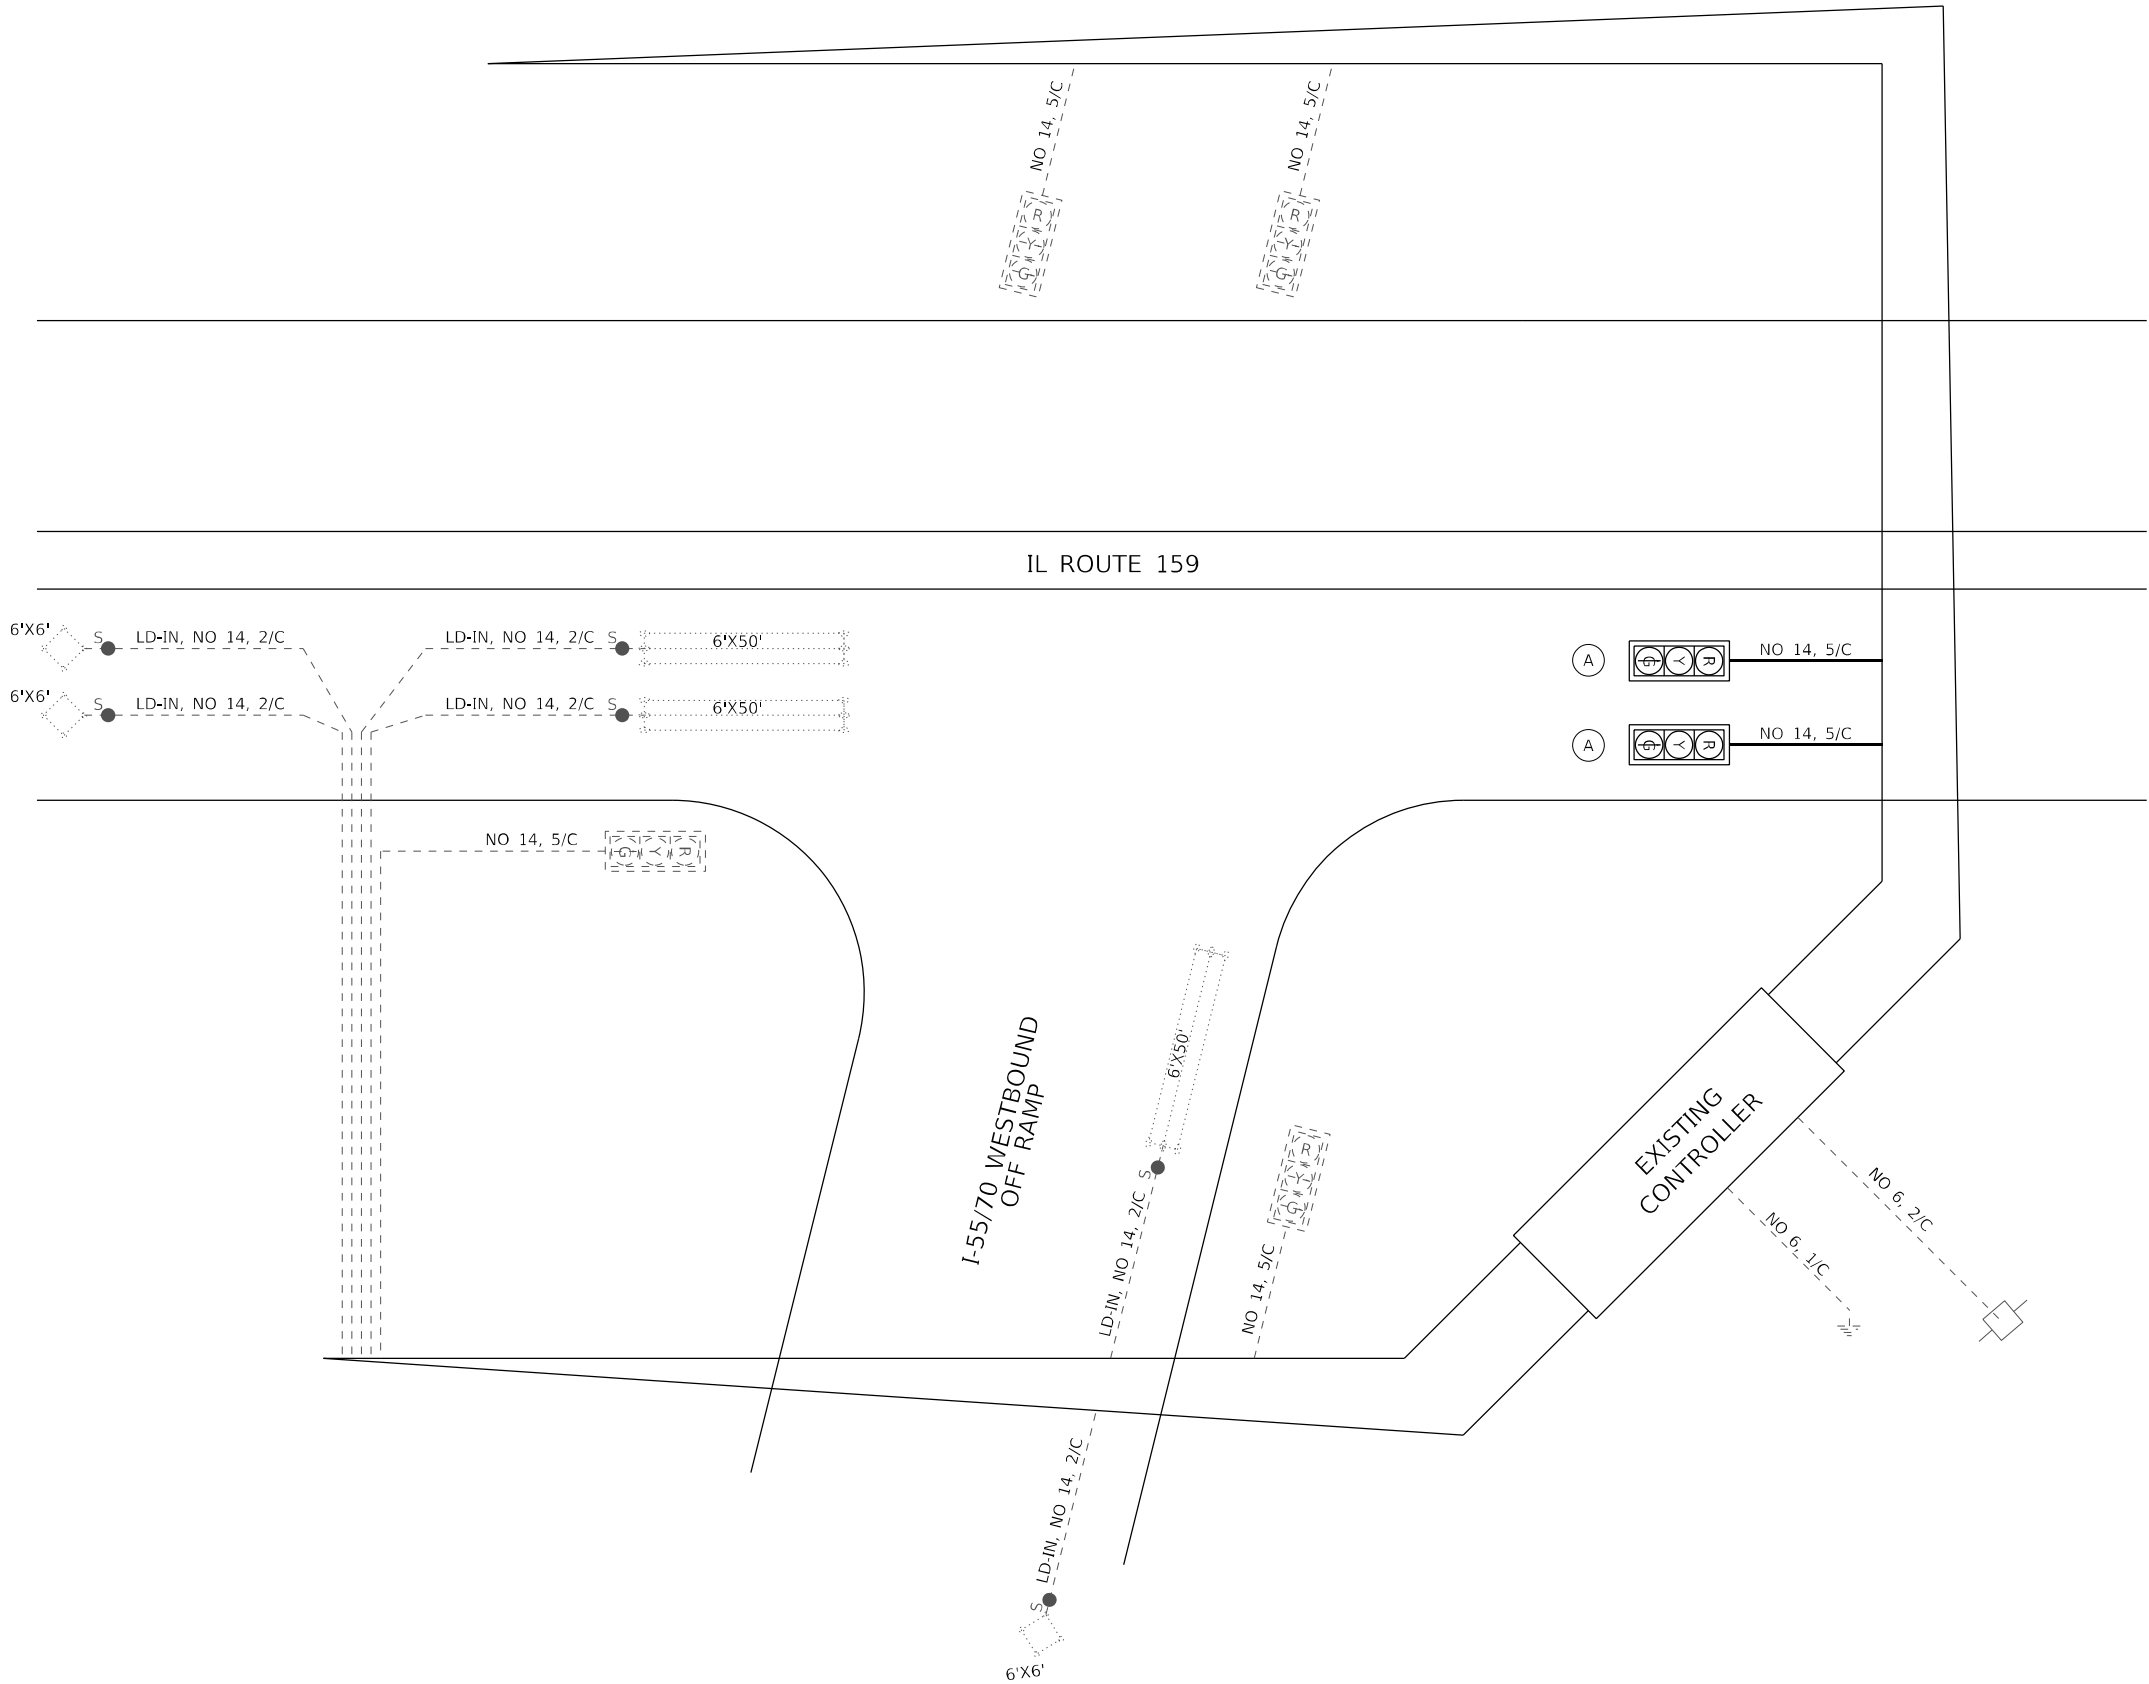

EXISTING TRAFFIC SIGNAL FACES

 


PROPOSED TRAFFIC SIGNAL FACES

(A) EXISTING SIGNAL HEAD AND BACK PLATE TO BE RELOCATED


CABLE DIAGRAM LEGEND

- PROPOSED ELECTRIC CABLE IN CONDUIT
- 2/C INDICATES NUMBER OF CONDUCTORS IN CABLE
- NO. 6 INDICATES AMERICAN WIRE (AWG) SIZE 6
- EXISTING ELECTRIC CABLE IN CONDUIT
- EXISTING PEDESTRIAN PUSH BUTTON
- EXISTING SERVICE INSTALLATION
- CABLE SPLICE

SECTION	COUNTY	TOTAL SHEETS	SHEET NO.
127-1R-3	MADISON	511	286
STA. 707+575 TO STA. 707+725			
EXISTING CONDITIONS:			

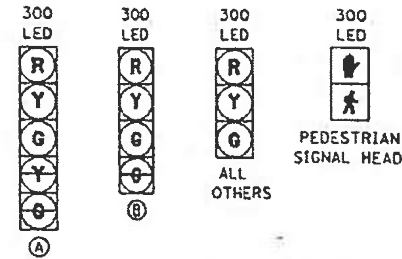

DETAIL E
NOT TO SCALE

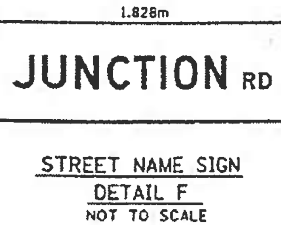

STREET NAME SIGN
DETAIL F
NOT TO SCALE




DETAIL H


PROPOSED TRAFFIC
SIGNAL FACES



MATCH LINE STA. 707+575

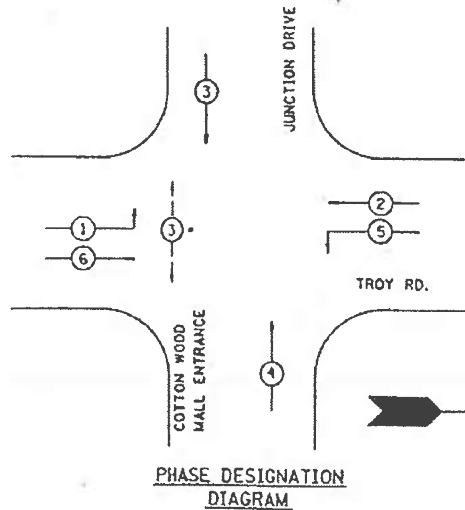

PHASE DESIGNATION
DIAGRAM


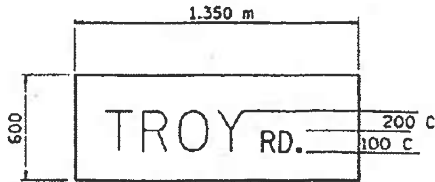


STREET NAME SIGN
DETAIL G
NOT TO SCALE

FULL-ACTUATED CONTROLLER
IN TYPE IV CABINET

EXISTING AND PROPOSED SEQUENCE OF OPERATION								
PHASE	1	2	3	4	5	6	7	8
MOVEMENT	NBLT	SB	EB	WB	SBLT	NB	NOT	NOT
CONCURRENT MOVEMENT PERMITTED	OR 5	OR 5	4	3	OR 1	OR 2	USED	USED

 • PEDESTRIAN SIGNAL ACTIVATION BY PUSHBUTTON ACTUATION, ONLY

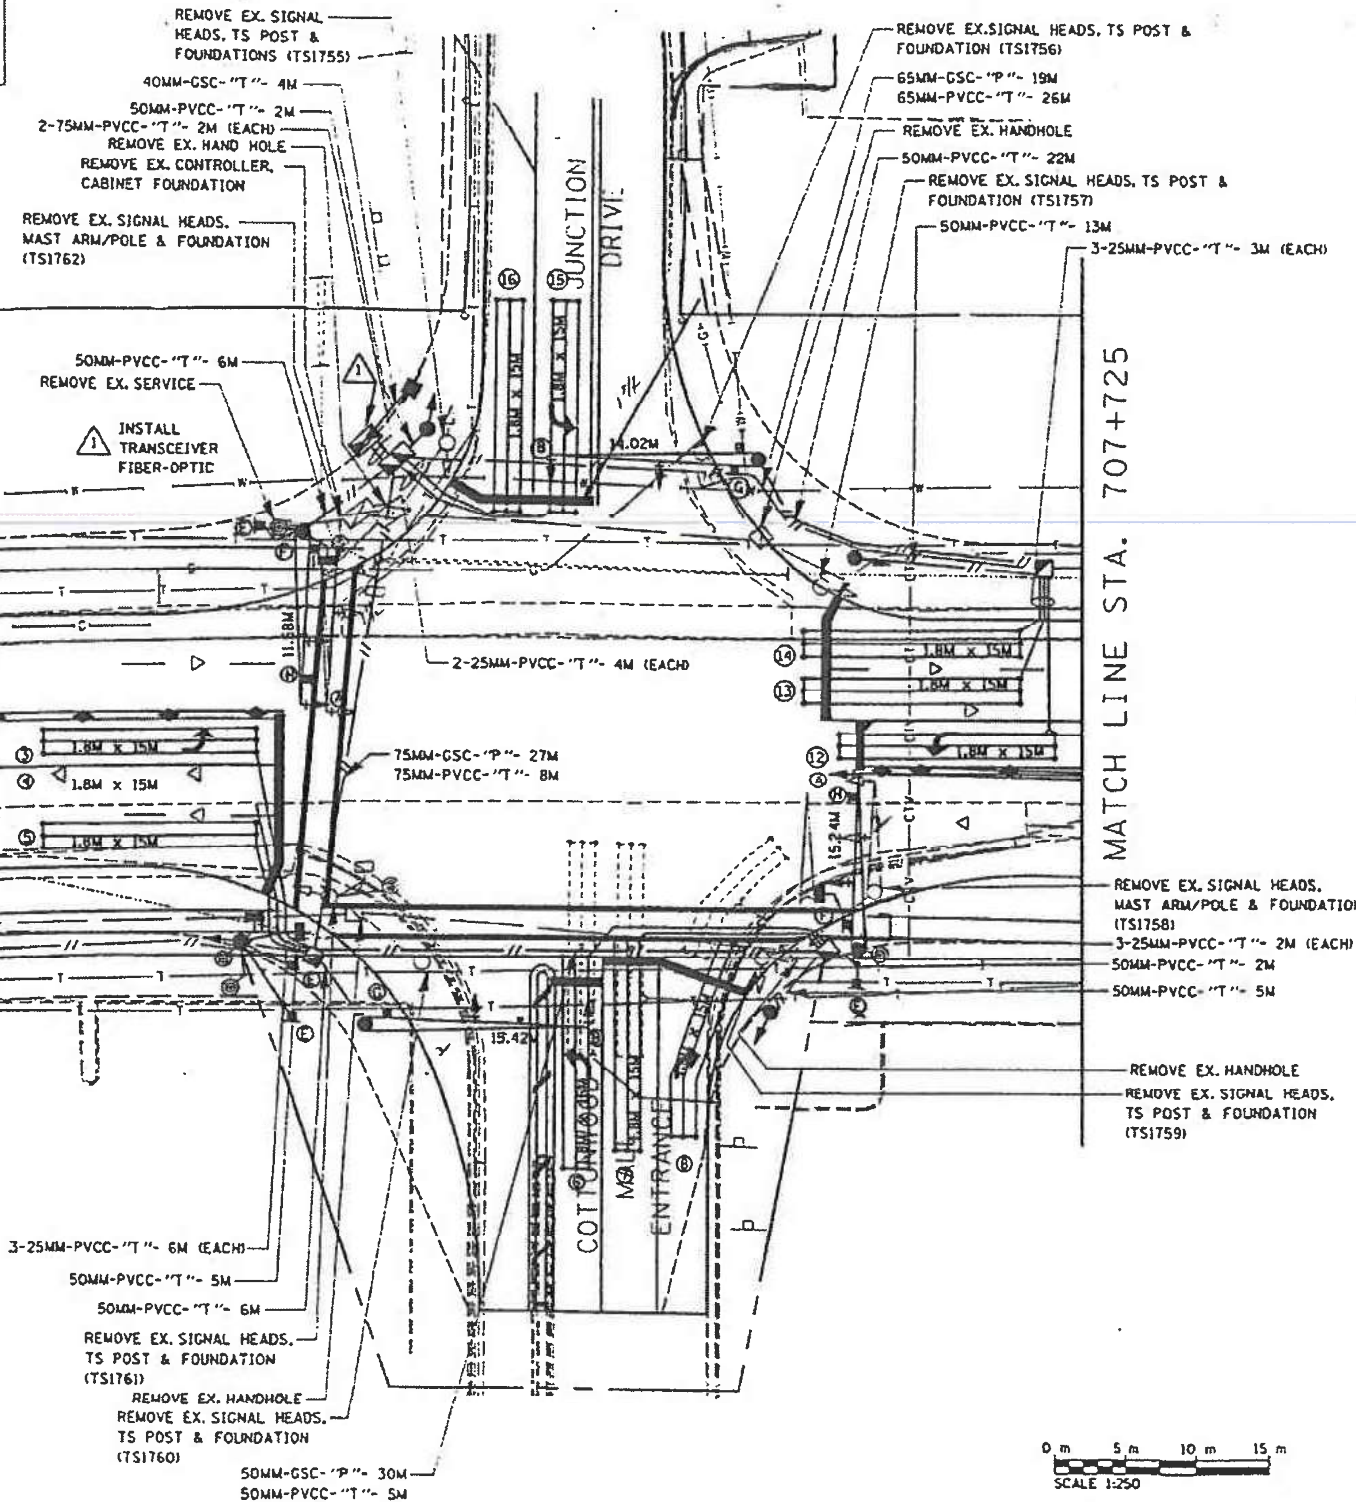

ALL DIMENSIONS ARE IN MM
UNLESS DESIGNATED OTHERWISE

REVISIONS	NAME	DATE

ILLINOIS DEPARTMENT OF TRANSPORTATION
JUNCTION RD./
COTTONWOOD MALL @ TROY RD.
TRAFFIC SIGNAL PLAN

FAP 600 ROUTE
SECTION 127-1R-3
MADISON COUNTY

DRAWN BY:

MODEL: Default
FILE NAME: 1103066_10DOT-DH08_PTB104_05090606_010_WC11_IL1591Design00076M87-2bdr-468111-11-11.dgn

HMG
ENGINEERS
IL PROF DESIGN FIRM 184,000899

USER NAME	= nseelhoefer
DESIGNED	-
DRAWN	-
PLOT SCALE	= 0.1667" / 1"
CHECKED	-
PLOT DATE	= 6/30/2022
DATE	-

DESIGNED	-
DRAWN	-
CHECKED	-
DATE	-


REVISED	-
REVISED	-
REVISED	-
REVISED	-

STATE OF ILLINOIS
DEPARTMENT OF TRANSPORTATION

AS BUILT
IL ROUTE 159 & I-55/70 N JUNCTION

SCALE: SHEET OF SHEETS STA. TO STA.

FAU RTE	SECTION	COUNTY	TOTAL SHEETS	SHEET NO.
8887	(122,122-1,30)RS-4	MADISON	328	257A
CONTRACT NO. 76M87				
ILLINOIS FED. AID PROJECT				

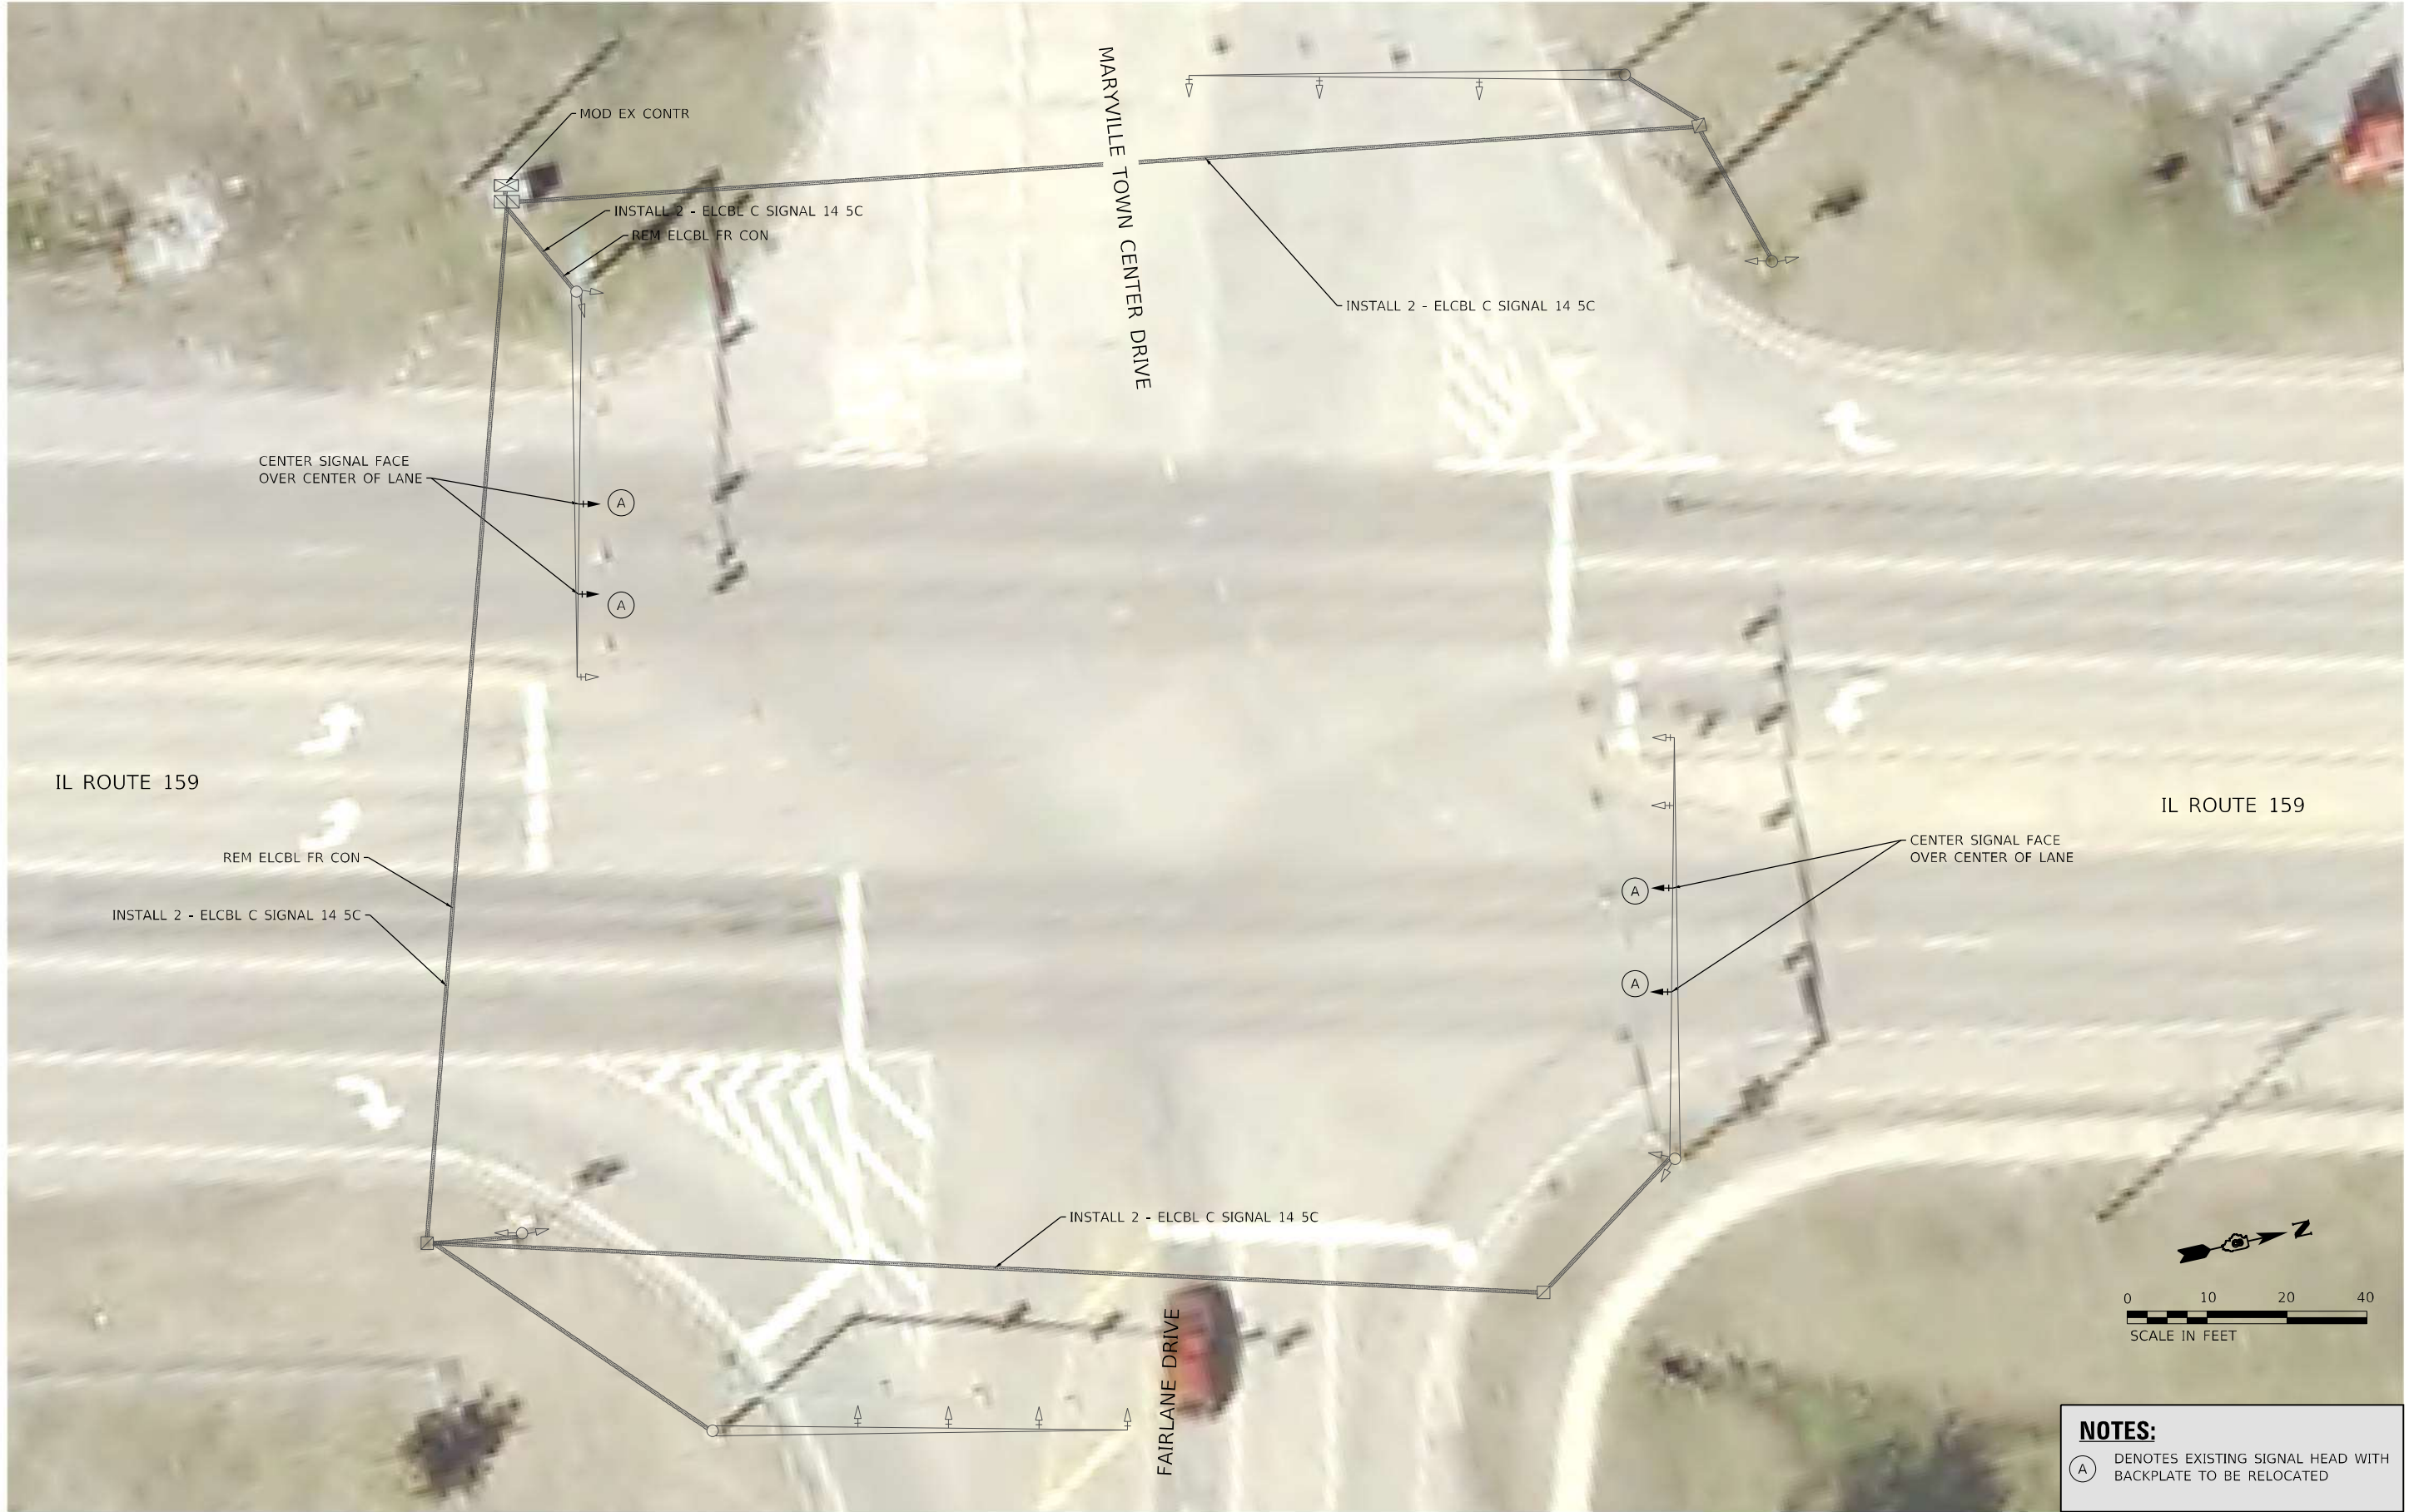

NOTES:

(A) DENOTES EXISTING SIGNAL HEAD WITH BACKPLATE TO BE RELOCATED

MODEL: Sheet 7 - Maryville Town Center
FILE NAME: 108249_05_159_02202010_010_W01_IL159_Traffic_Signal_Upgrade.dgn
C:\Users\hmc\OneDrive\Documents\108249_05_159_02202010_010_W01_IL159_Traffic_Signal_Upgrade.dgn

HMG
ENGINEERS
IL PROF DESIGN FIRM 184,000899

USER NAME = nseelhoefer	DESIGNED -	REVISED -
	DRAWN -	REVISED -
PLOT SCALE = 20,000' / in.	CHECKED -	REVISED -
PLOT DATE = 6/30/2022	DATE -	REVISED -

STATE OF ILLINOIS
DEPARTMENT OF TRANSPORTATION

TRAFFIC SIGNAL PLANS			
IL ROUTE 159 & MARYVILLE TOWN CENTER DRIVE /FAIRLANE DRIVE			
SCALE: 1" = 10'	SHEET TS 7 OF 31 SHEETS	STA.	TO STA.

F.A.P. RTE.	SECTION	COUNTY	TOTAL SHEETS	SHEET NO.
600	(122,122-1,30)RS-4	MADISON	328	258
CONTRACT NO. 76M87				
ILLINOIS FED. AID PROJECT				

MODEL: Sheet 22 - Town Center
FILE NAME: 108249_009_199_0278249_010_WO1_IL159_Traffic_Signal_Upgrade\Card_Sheets\0876M87-Cable_Diagrams.dgn



USER NAME	= nseelhoefer
PLOT SCALE	= 10,0000 ' / in.
PLOT DATE	= 6/30/2022


DESIGNED	-
DRAWN	-
CHECKED	-
DATE	-

REVISED	-
REVISED	-
REVISED	-
REVISED	-


STATE OF ILLINOIS
DEPARTMENT OF TRANSPORTATION

CABLE DIAGRAM			
IL ROUTE 159 & MARYVILLE TOWN CENTER DRIVE /FAIRLANE DRIVE			
SCALE: NTS	SHEET TS 22 OF 31 SHEETS	STA.	TO STA.


F.A.P. RTE.	SECTION	COUNTY	TOTAL SHEETS	SHEET NO.
600	(122,122-1,30)RS-4	MADISON	328	259
CONTRACT NO. 76M87				
ILLINOIS		FED. AID PROJECT		

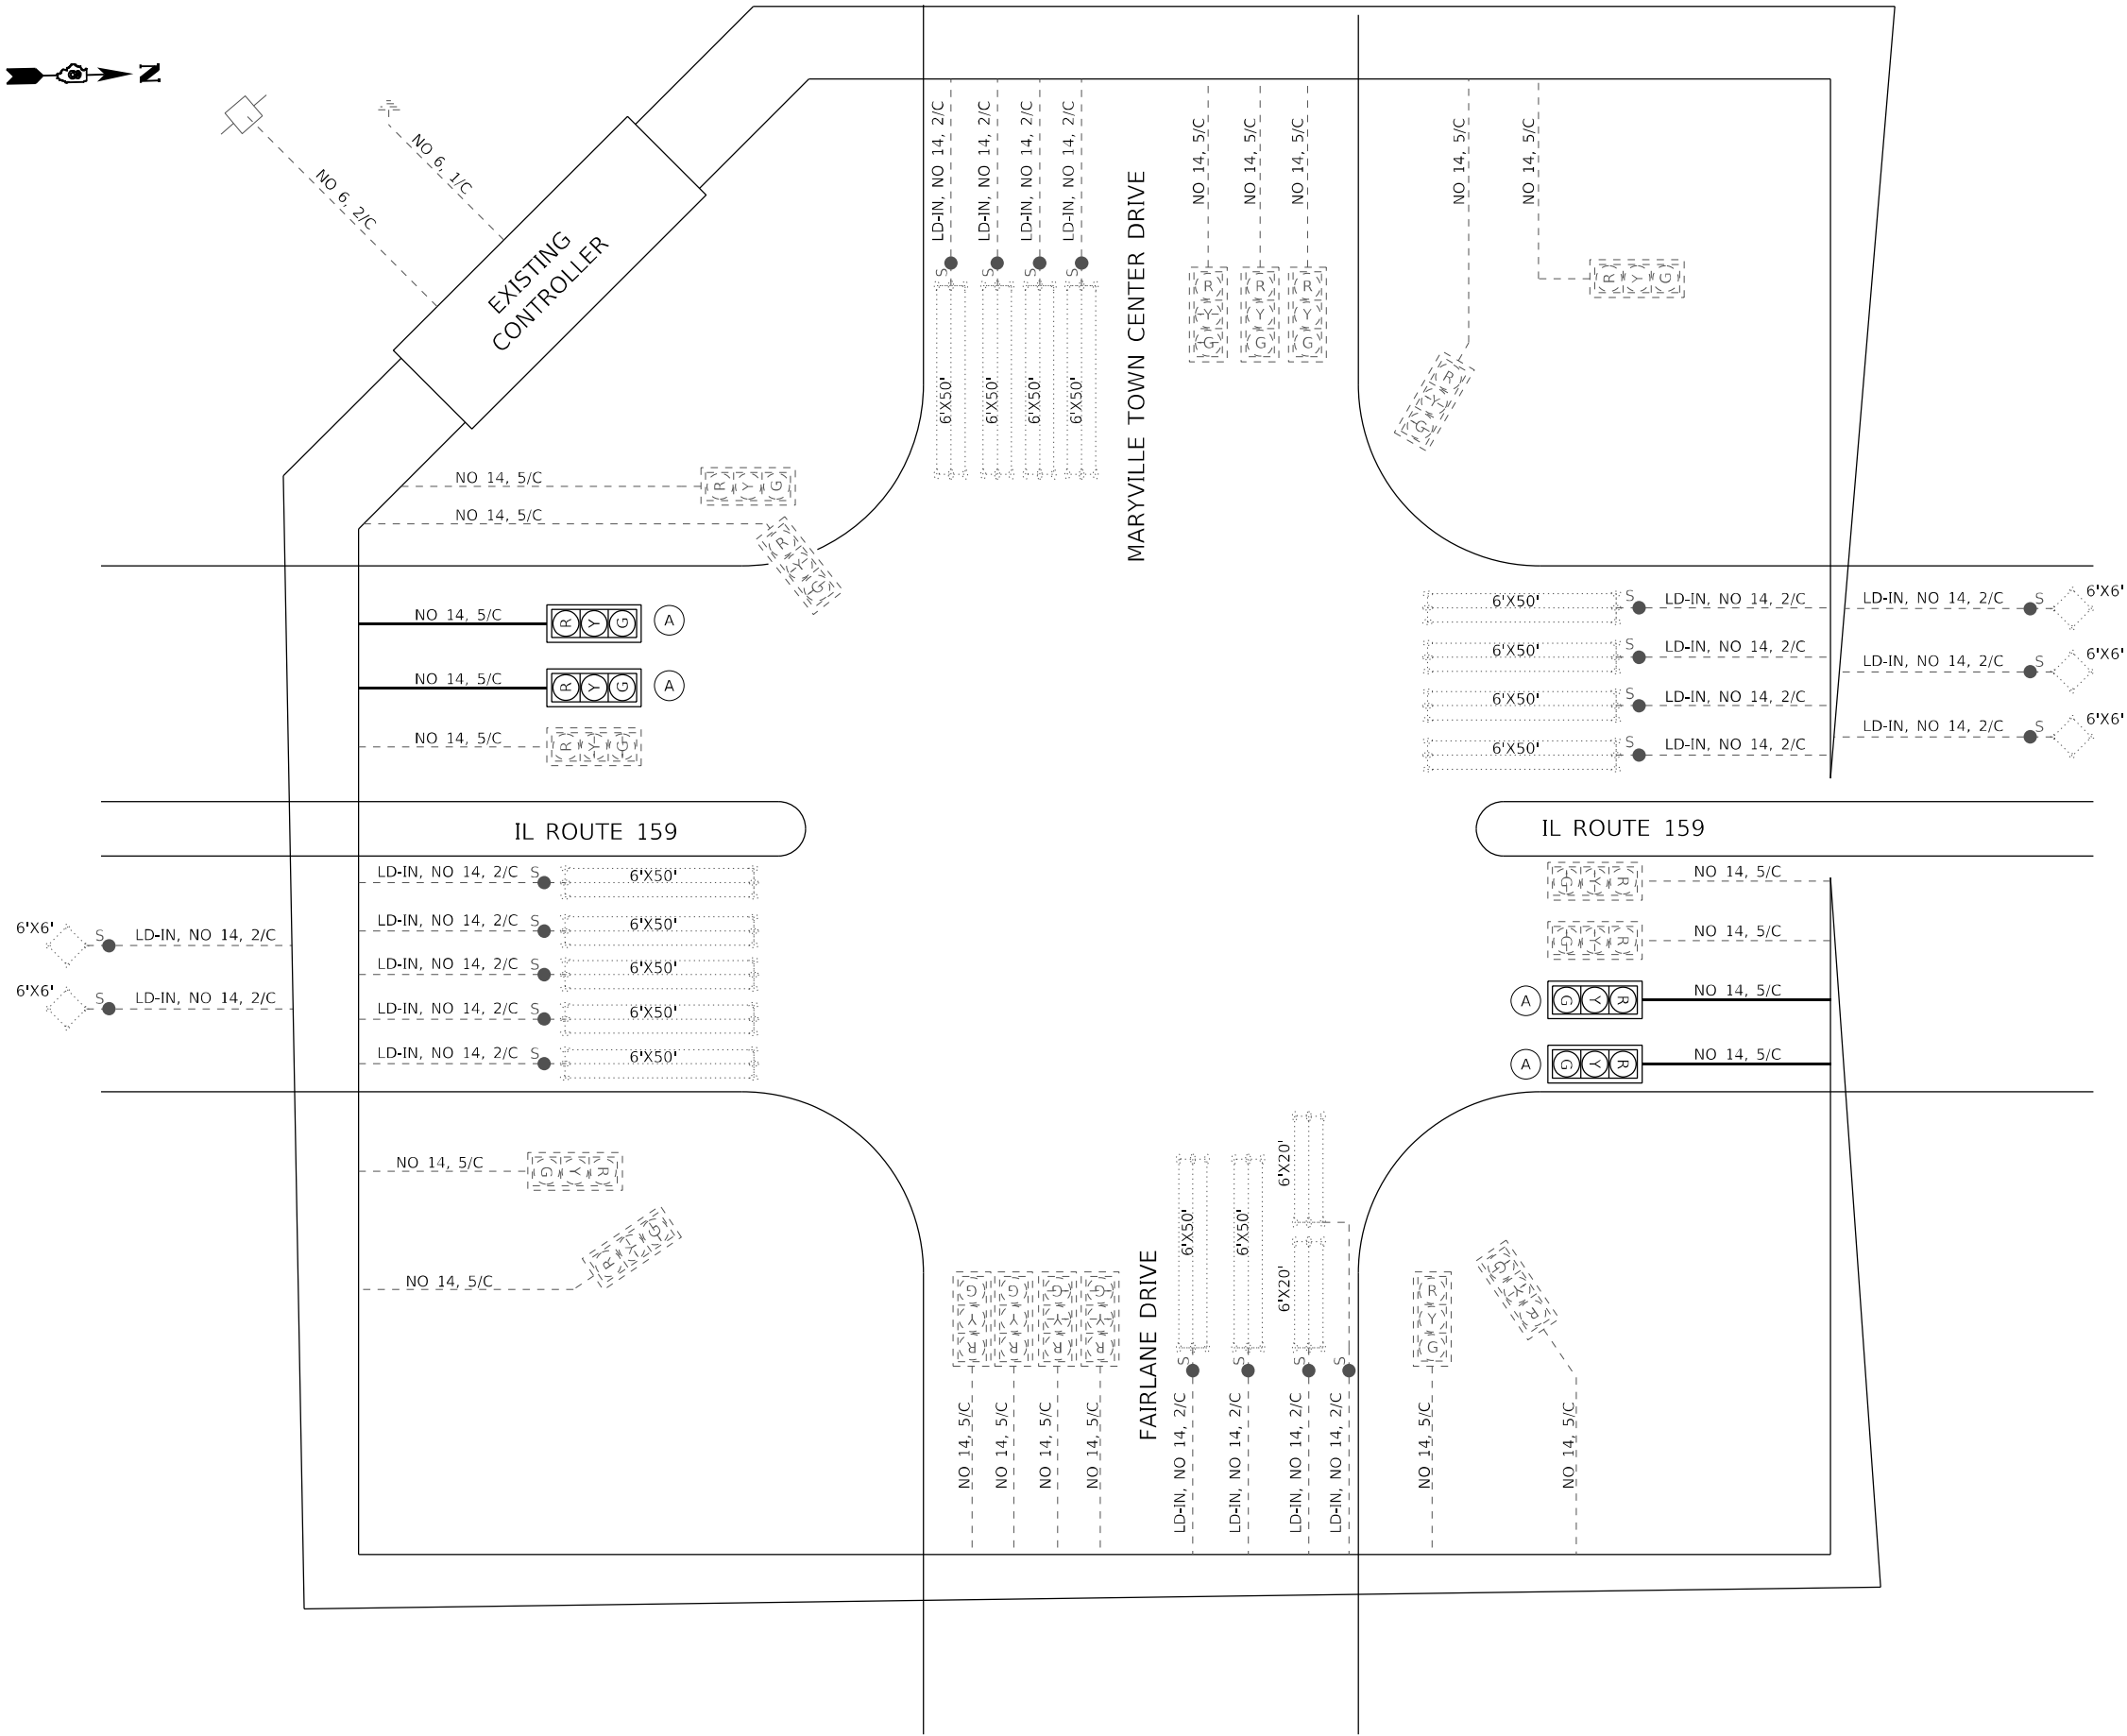

EXISTING TRAFFIC SIGNAL FACES

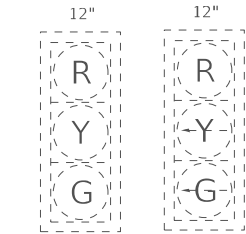

PROPOSED TRAFFIC SIGNAL FACES

 

(A) EXISTING SIGNAL HEAD AND BACK PLATE TO BE RELOCATED




CABLE DIAGRAM LEGEND

- PROPOSED ELECTRIC CABLE IN CONDUIT
- 2/C INDICATES NUMBER OF CONDUCTORS IN CABLE
- NO. 6 INDICATES AMERICAN WIRE (AWG) SIZE 6
- EXISTING ELECTRIC CABLE IN CONDUIT
- EXISTING PEDESTRIAN PUSH BUTTON
- EXISTING SERVICE INSTALLATION
- CABLE SPLICE


CONTROLLER PHASING

PROPOSED								
PHASE #	1	2	3	4	5	6	7	8
MOVEMENT	SB LT	NR	WB LT	NR	NR LT	SB	EB LT	WB
CONCURRENT MOVEMENT PERMITTED	5 OR 6	5 OR 6	7 OR 8	7 OR 8	1 OR 2	1 OR 2	3 OR 4	3 OR 4


TRAFFIC SIGNAL FACES

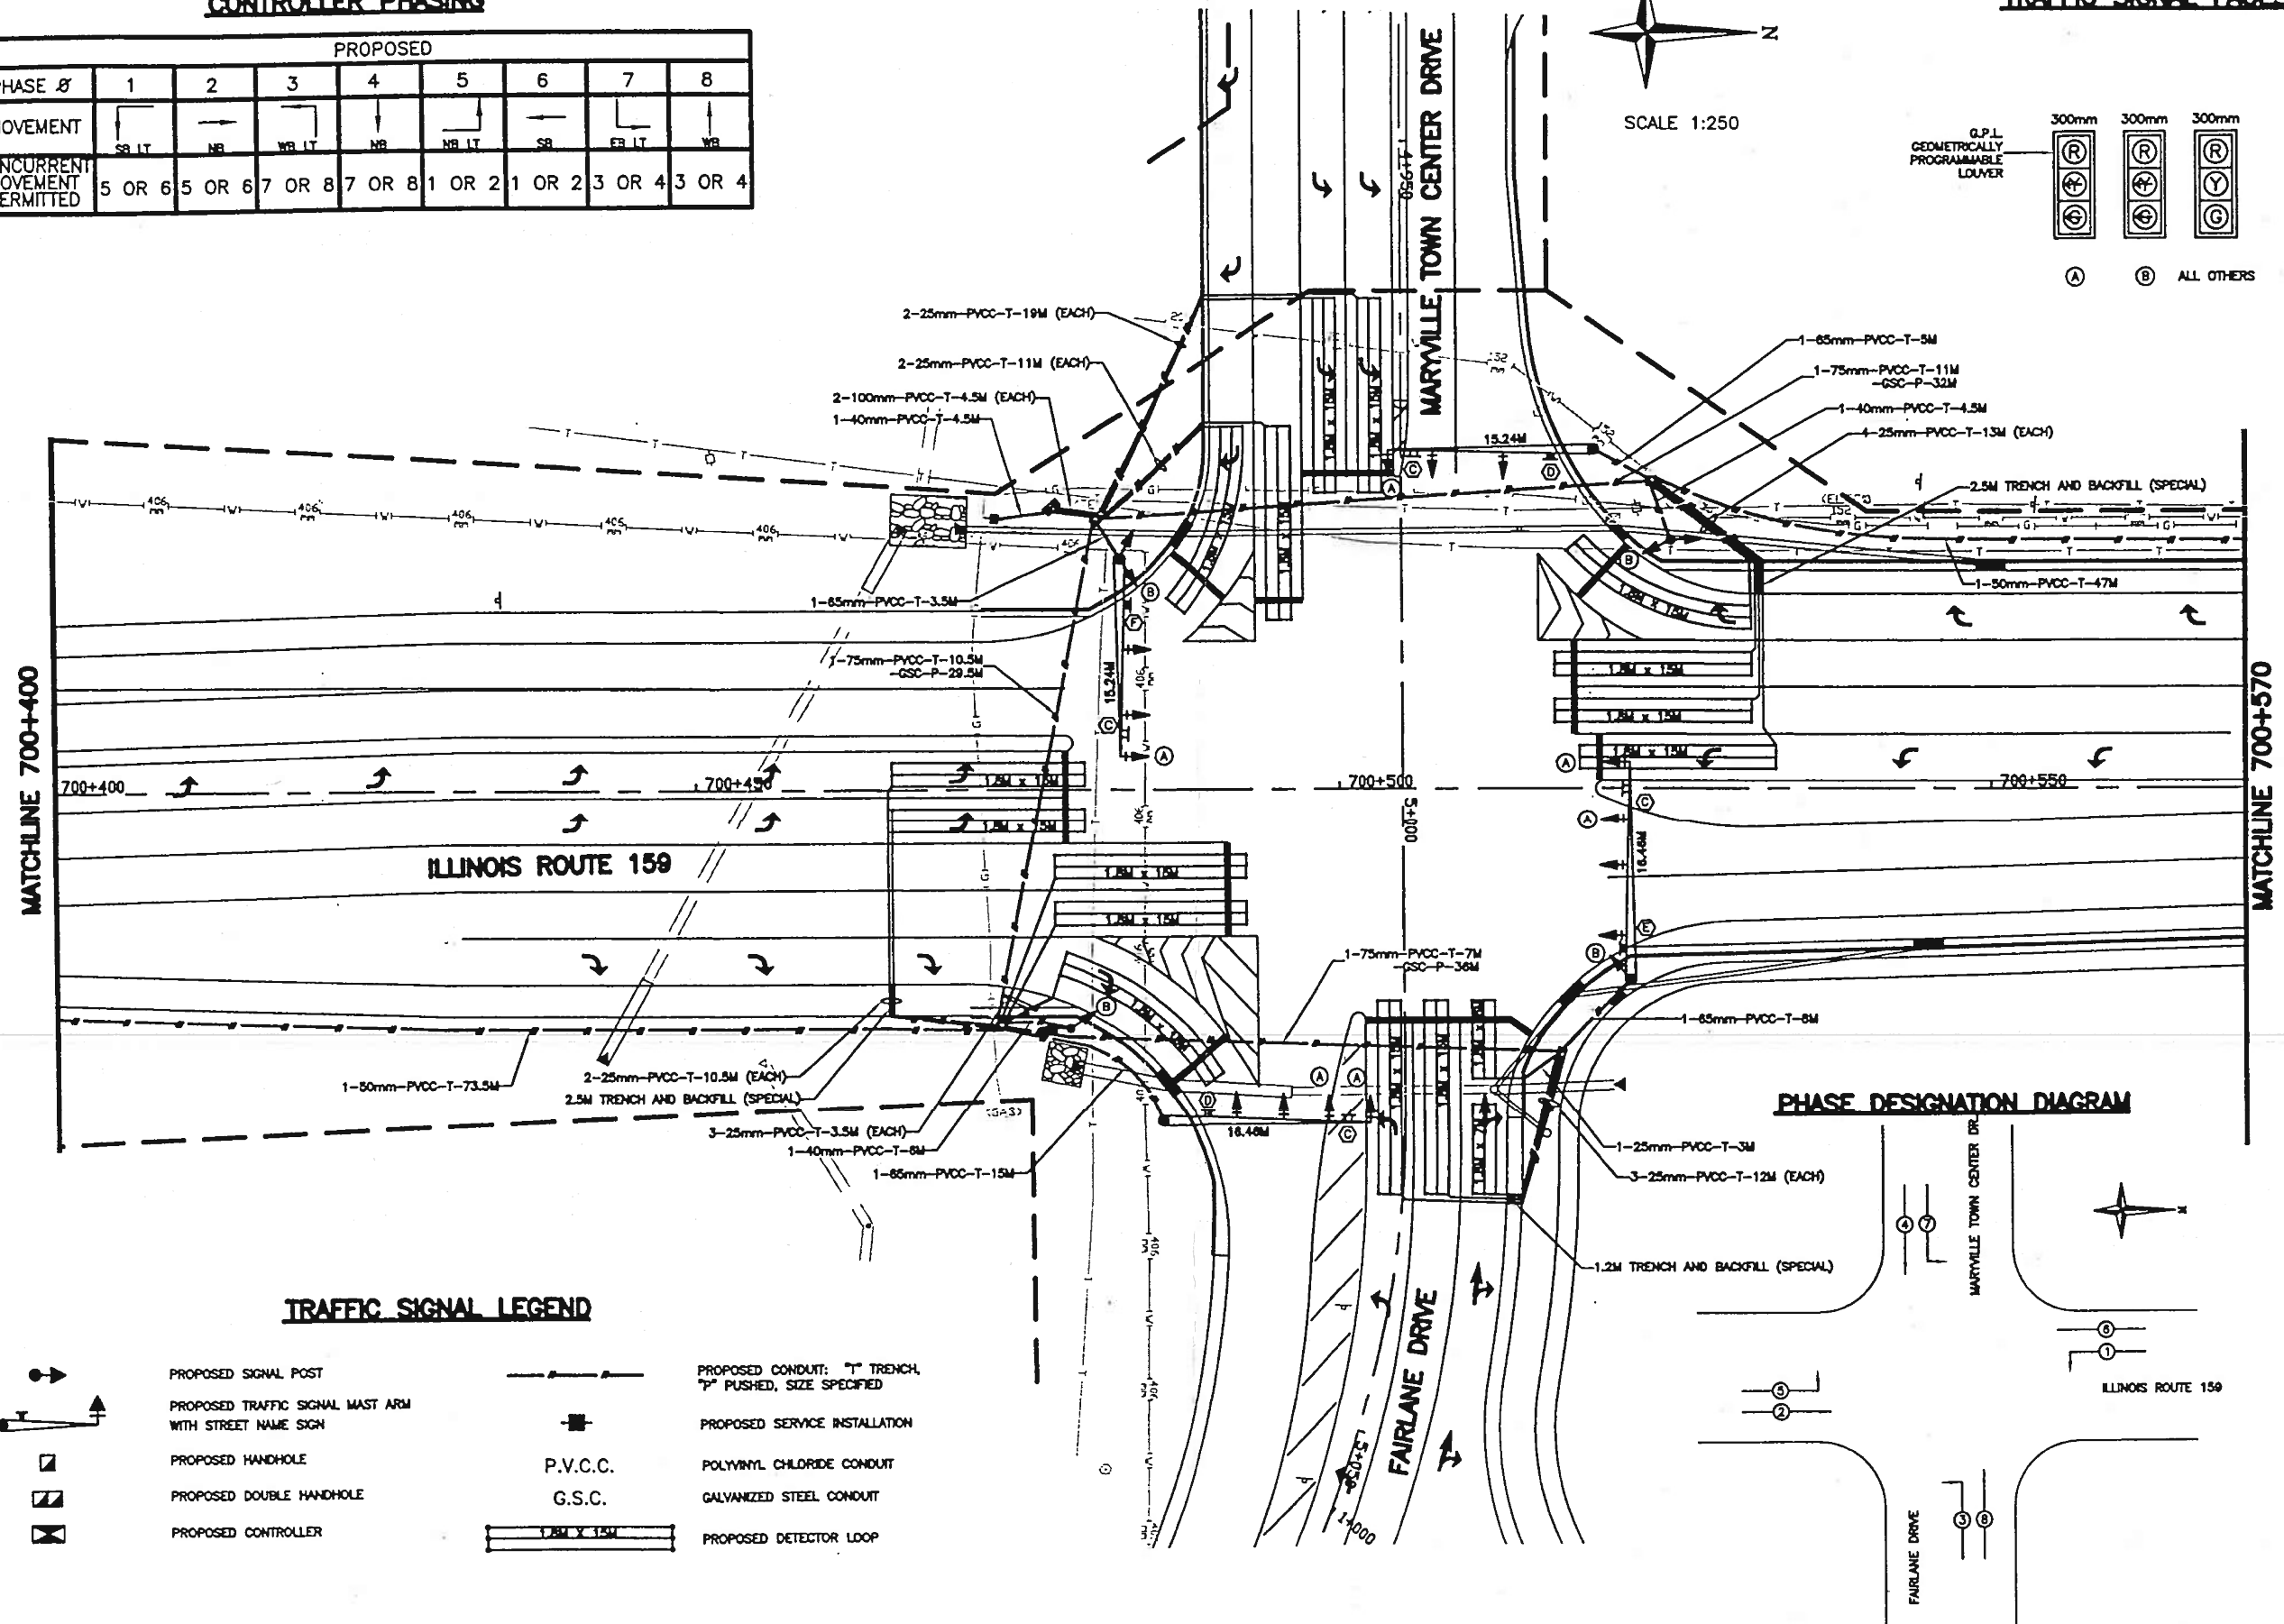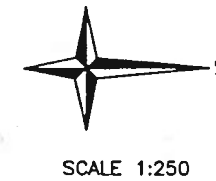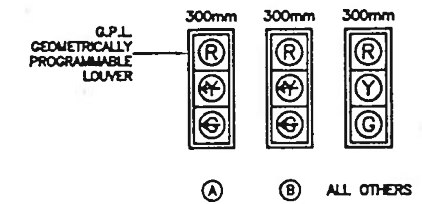

TRAFFIC SIGNAL LEGEND

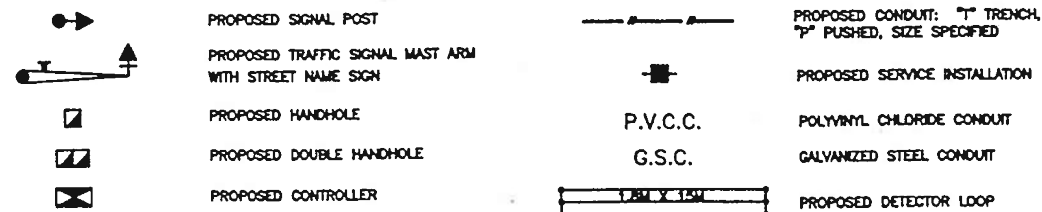

PHASE DESIGNATION DIAGRAM

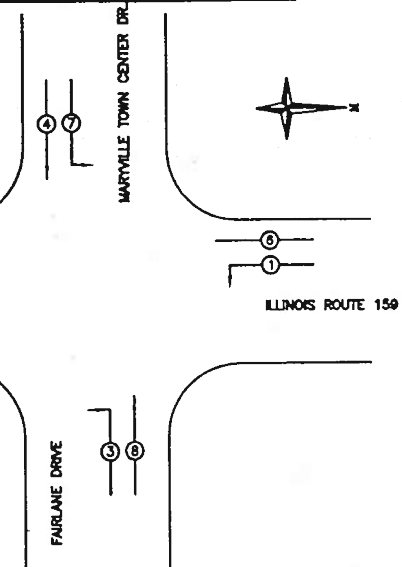

MODEL: Default
FILE NAME: I:\03066_1\DOT Dwg\PTB194_05190666_010_WC11 IL 159 Design\DOT 76M87-2-dr-48-11-15.dgn

HMG
ENGINEERS
IL PROF DESIGN FIRM 184,000899



USER NAME = nseelhoefer	DESIGNED -	REVISED -
PLOT SCALE = 0.1667" / 1'	DRAWN -	REVISED -
PLOT DATE = 6/30/2022	CHECKED -	REVISED -
	DATE -	REVISED -

STATE OF ILLINOIS
DEPARTMENT OF TRANSPORTATION

AS BUILT
IL ROUTE 159 & MARYVILLE TOWN CENTER
DRIVE/FAIRLANE DRIVE

SCALE: SHEET OF SHEETS STA. TO STA.

FAU RTE	SECTION	COUNTY	TOTAL SHEETS	SHEET NO.
8887	(122,122-1,30)RS-4	MADISON	328	259A
CONTRACT NO. 76M87				
ILLINOIS FED. AID PROJECT				

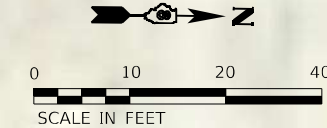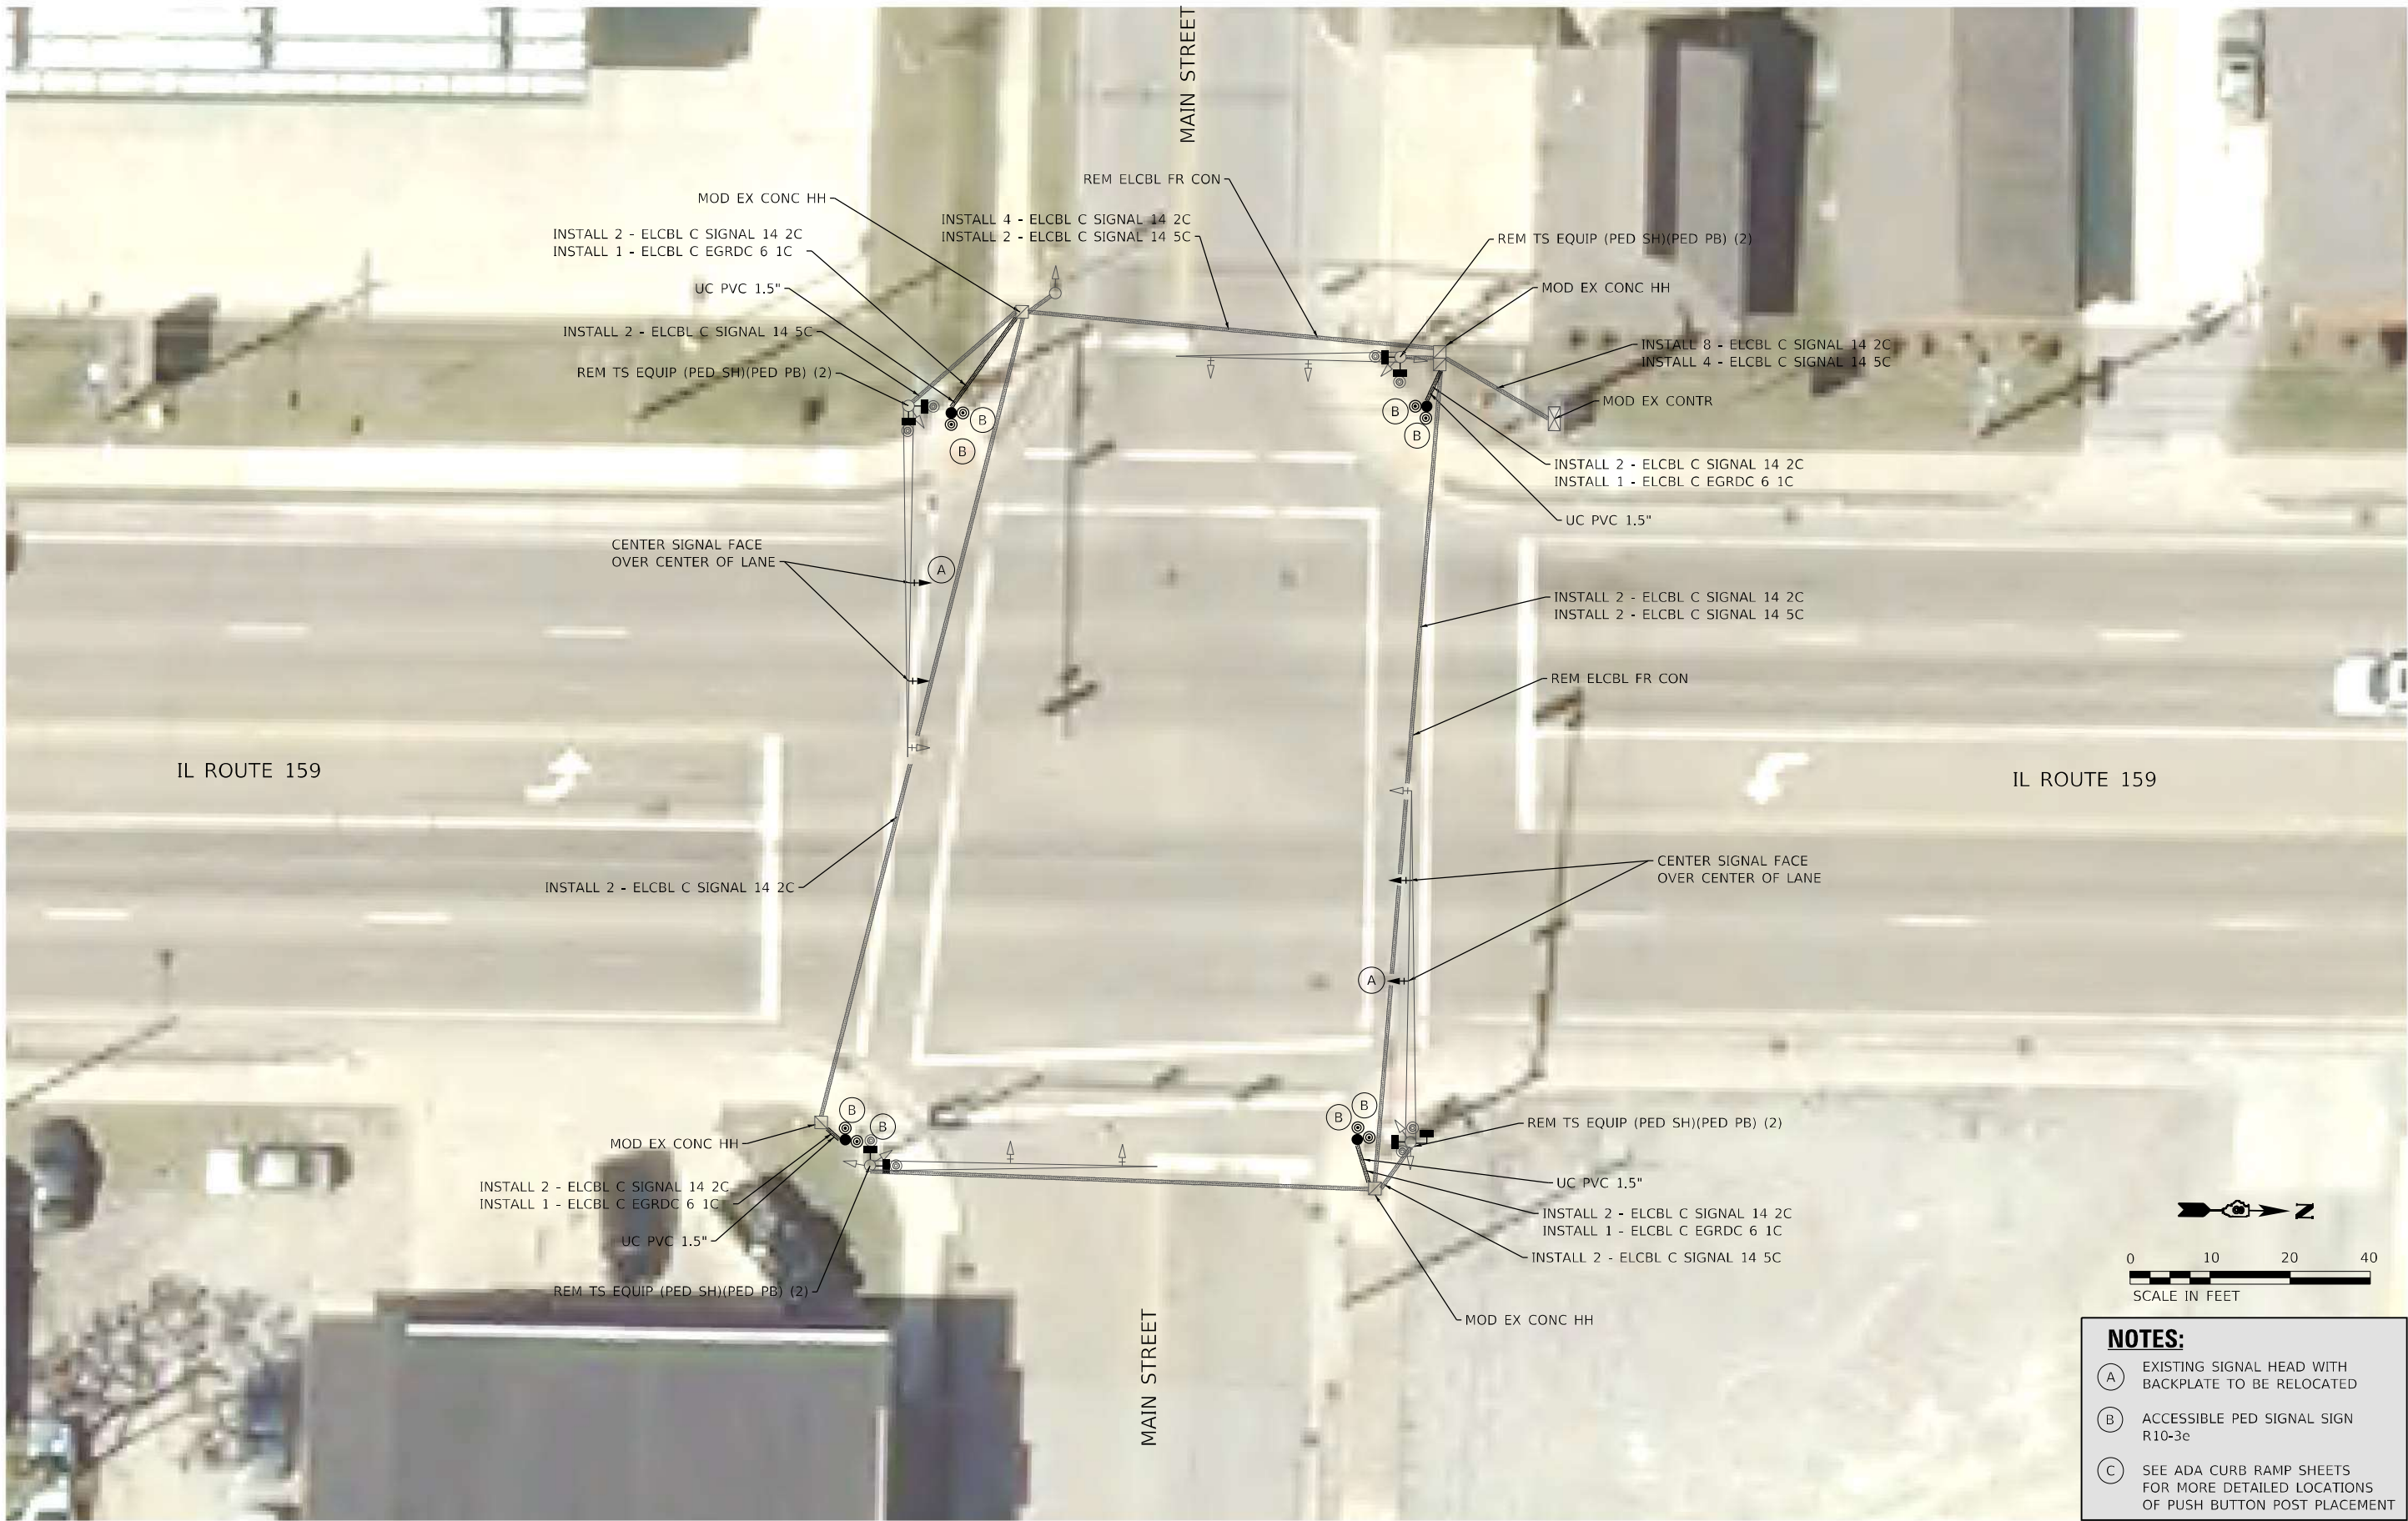

- NOTES:**
- (A) EXISTING SIGNAL HEAD WITH BACKPLATE TO BE RELOCATED
 - (B) ACCESSIBLE PED SIGNAL SIGN R10-3e
 - (C) SEE ADA CURB RAMP SHEETS FOR MORE DETAILED LOCATIONS OF PUSH BUTTON POST PLACEMENT

MODEL: Sheet 8 - Main
FILE NAME: 108249_08_199_03218249_010.W01_IL159_Traffic_Signal_Upgrade.dgn

HMG
ENGINEERS
IL PROF DESIGN FIRM 184,000899

USER NAME	= nseelhoefer	DESIGNED	-	REVISED	-
		DRAWN	-	REVISED	-
PLOT SCALE	= 20,0000' / in.	CHECKED	-	REVISED	-
PLOT DATE	= 6/30/2022	DATE	-	REVISED	-

STATE OF ILLINOIS
DEPARTMENT OF TRANSPORTATION

TRAFFIC SIGNAL PLANS			
IL ROUTE 159 & MAIN STREET			
SCALE: 1" = 10'	SHEET TS 8 OF 31 SHEETS	STA.	TO STA.

F.A.P. RTE.	SECTION	COUNTY	TOTAL SHEETS	SHEET NO.
600	(122,122-1,30)RS-4	MADISON	328	260
				CONTRACT NO. 76M87
				ILLINOIS FED. AID PROJECT

MODEL: Sheet 23 - Main
FILE NAME: 1082249_703_199_02182249_010_W01_IL159_Traffic_Signal_Upgrade\Card_Sheets\0876M87-Cable_Diagrams.dgn



IL PROF DESIGN FIRM 184,000899

USER NAME = nseelhoefer
PLOT SCALE = 10,0000 ' / in.
PLOT DATE = 6/30/2022

DESIGNED -
DRAWN -
CHECKED -
DATE -

REVISED -
REVISED -
REVISED -
REVISED -

STATE OF ILLINOIS
DEPARTMENT OF TRANSPORTATION

CABLE DIAGRAM
IL ROUTE 159 & MAIN STREET

SCALE: NTS

SHEET TS 23 OF 31 SHEETS

STA.

TO STA.

F.A.P.
RTE.
600

SECTION
(122,122-1,30)RS-4



COUNTY
MADISON

TOTAL
SHEETS
328


SHEET
NO.
261

CONTRACT NO. 76M87

ILLINOIS FED. AID PROJECT

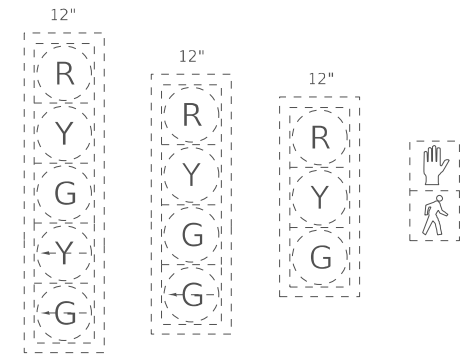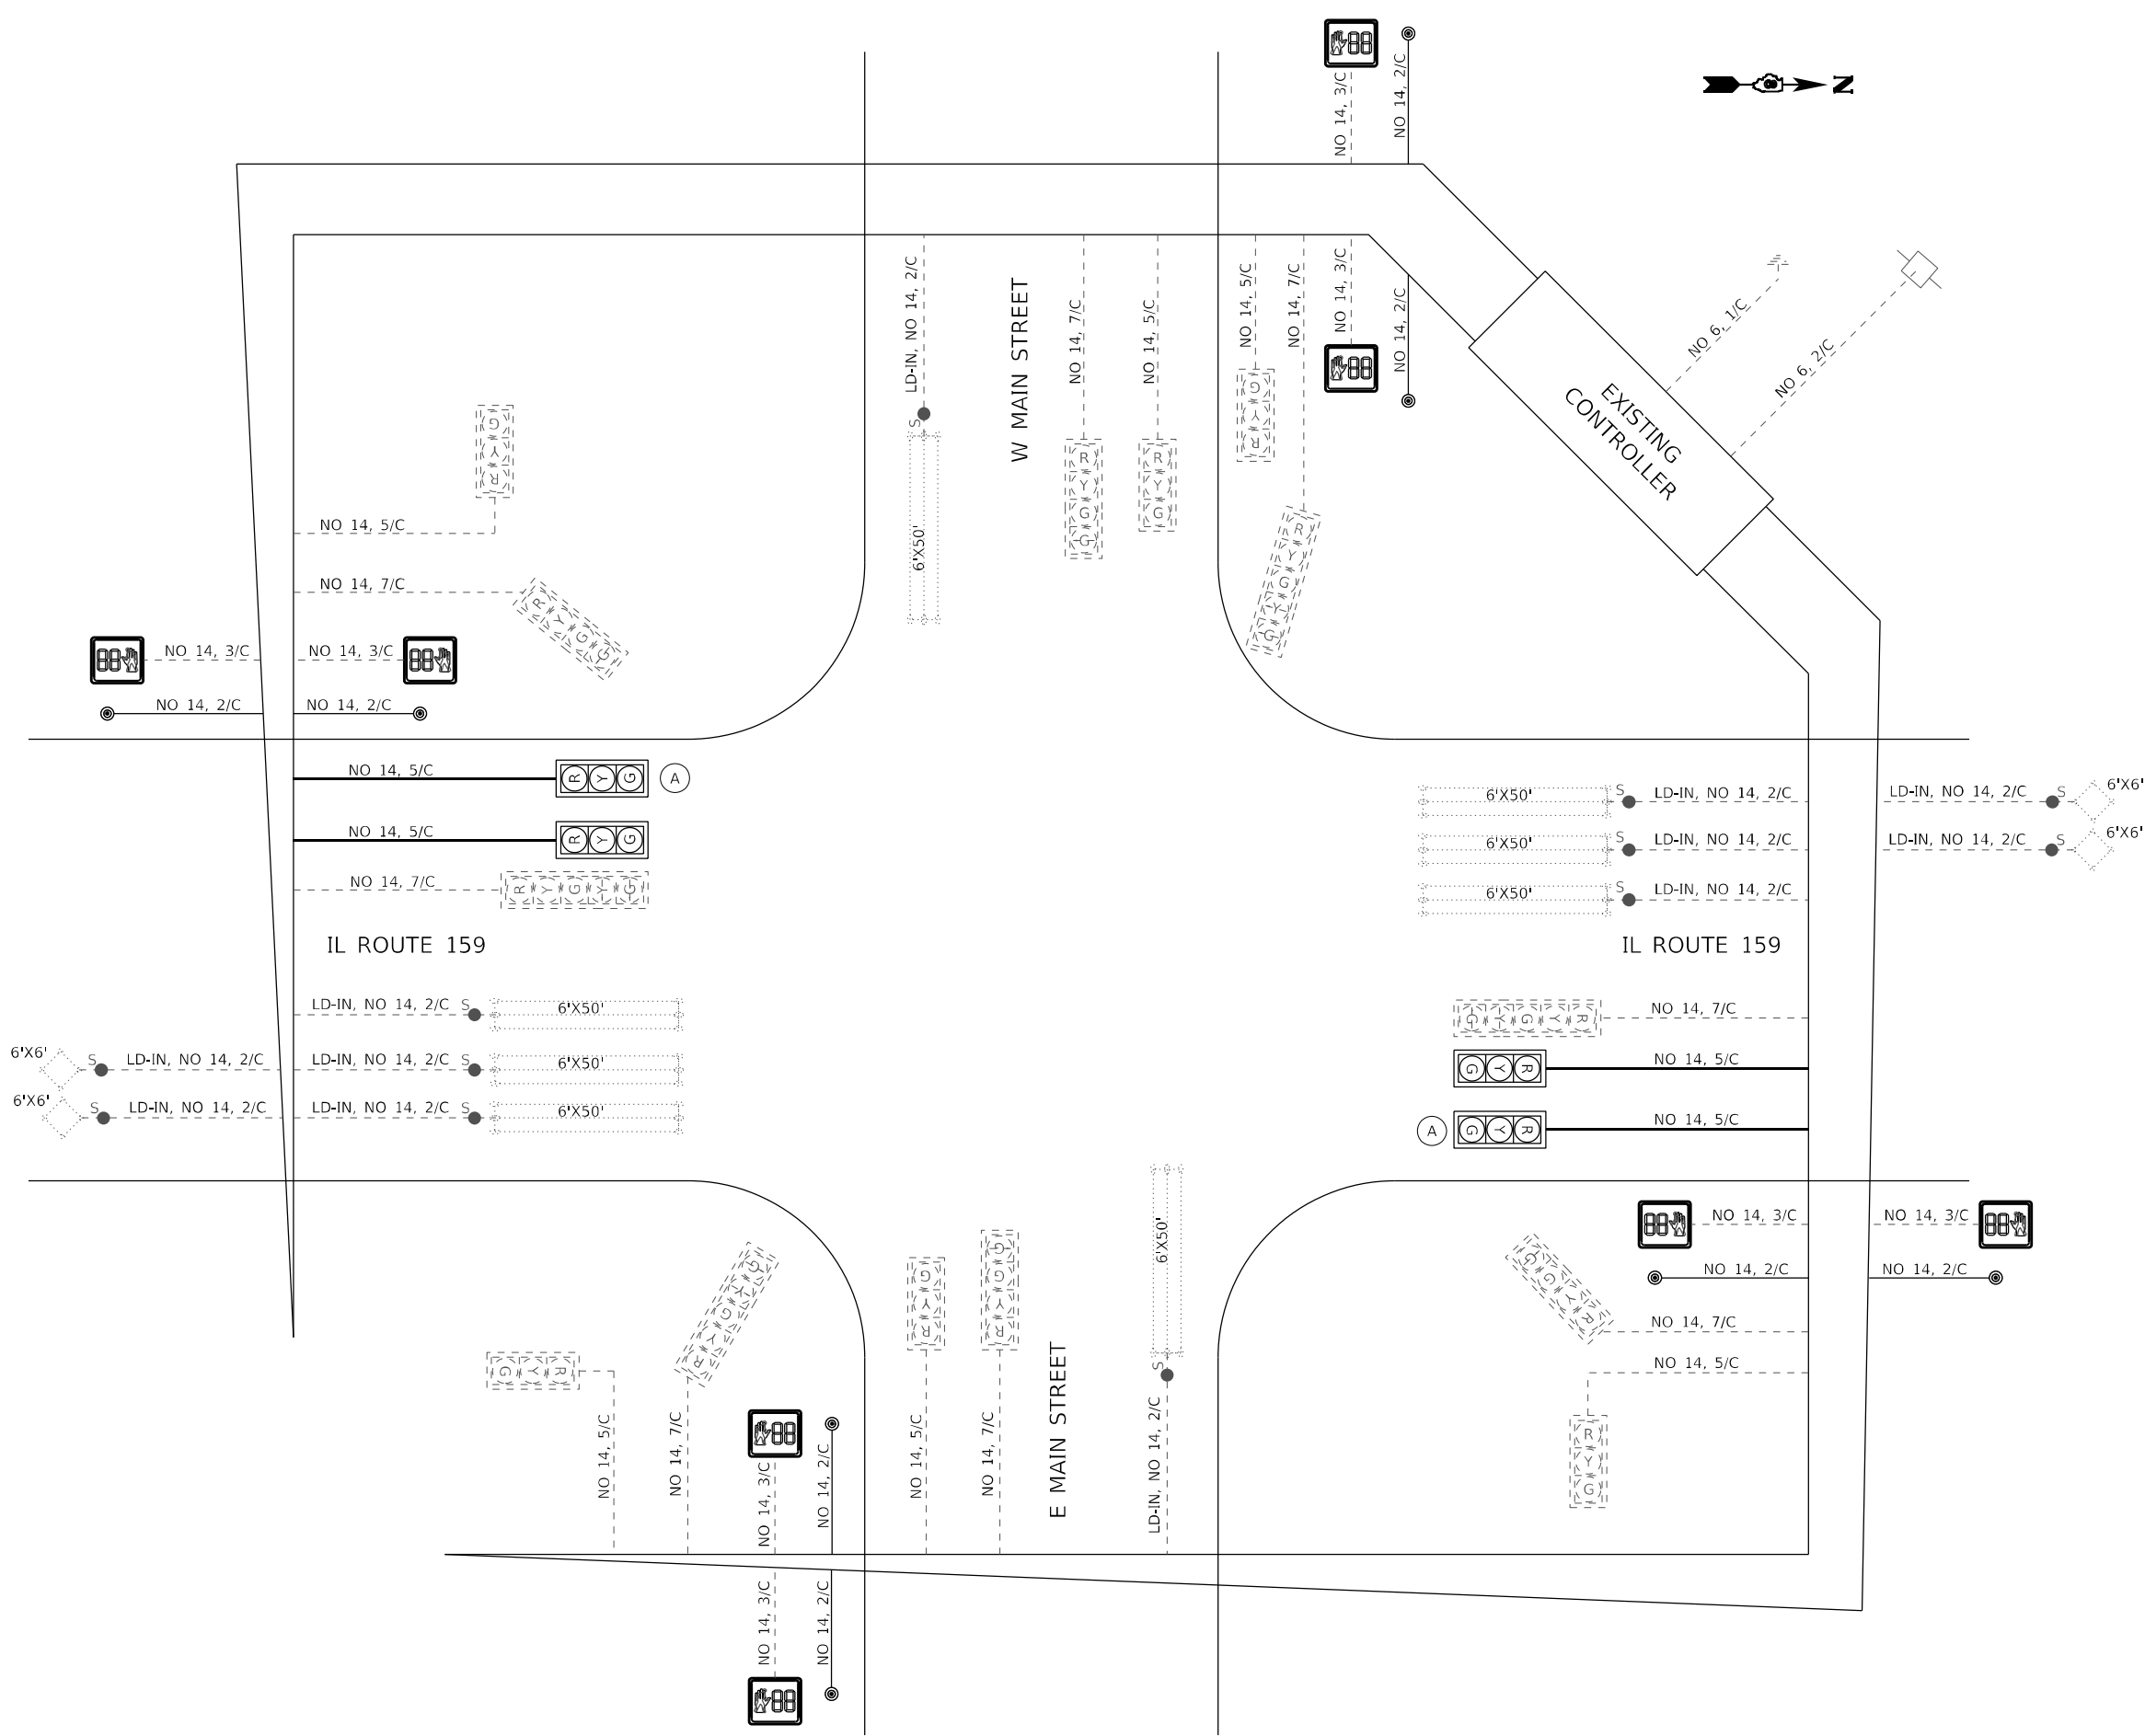

EXISTING TRAFFIC SIGNAL FACES

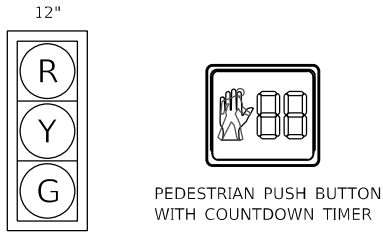

PROPOSED TRAFFIC SIGNAL FACES

(A) EXISTING SIGNAL HEAD AND BACK PLATE TO BE RELOCATED

CABLE DIAGRAM LEGEND

- PROPOSED PEDESTRIAN PUSH BUTTON
- PROPOSED ELECTRIC CABLE IN CONDUIT
- INDICATES NUMBER OF CONDUCTORS IN CABLE
- INDICATES AMERICAN WIRE (AWG) SIZE 6
- EXISTING ELECTRIC CABLE IN CONDUIT
- EXISTING PEDESTRIAN PUSH BUTTON
- EXISTING SERVICE INSTALLATION
- CABLE SPLICE

A.A. NO.	SECTION	COUNTY	TRAIL MILEAGE	DATE OF
600	12TR-P	MADISON	118	79
STA.		TO STA.		
EXISTING CONDITIONS: Gravel Survey				

- ELECTRICAL GENERAL NOTES**

 1. The location of all detector loops shall be approved by the engineer before any slots are sawed in the pavement.
 2. Detector loop lead-in splice shall be made in a handhole per Section T421 of the Standard Specifications for Traffic Control Items. Conductors shall be soldered prior to applying compound. Rosin-core solder shall be used.
 3. Call delay shall not function when the related phases are in the green mode.
 4. "Call Carry-over" shall function only when the related phases are in the green mode.
 5. All induction loop detector amplifiers supplied for this project shall have the capacity of operating with both delay and extension modes active, if a time setting is programmed.
 6. Slope handhole covers to match proposed grade elevations.
 7. Locate underground cables prior to attempting to construct this project.
 8. Abandon existing conduits and cables in place.
 9. Detector loops shall be placed in the pavement after milling and prior to resurfacing.

TRAFFIC SIGNALS LEGEND

 - GSC Galvanized Steel Conduit
 - PVCC Polyvinyl Chloride Conduit
 - Existing Traffic Signal Mast Arm
 - Existing Handhole
 - Existing Detector Loop
 - Existing Controller
 - Existing Service Installation
 - Existing Signal Head, Pedestrian
 - Existing Pedestrian Pushbutton Detector
 - Existing Galvanized Steel Conduit
 - Proposed Handhole
 - Proposed Heavy Duty Handhole
 - Proposed Detector Loop
 - Proposed Conduit: "T" Trench, "P" Push, Size Specified

ILLINOIS DEPARTMENT OF TRANSPORTATION
TRAFFIC SIGNAL PLANS
F.A. ROUTE 600
SECTION 127R-2
MADISON COUNTY
DRAWN BY C.A.D.

REVISIONS
NAME DATE

SCALE: 1" = 20'

6SC	Galvanized Steel Conduit
PVCC	Polyvinyl Chloride Conduit
	Existing Traffic Signal Mast Arm
	Existing Handhole
	Existing Detector Loop
	Existing Controller
	Existing Service Installation
	Existing Signal Head, Pedestrian
	Existing Pedestrian Pushbutton Detector
	Existing Galvanized Steel Conduit
	Proposed Handhole
	Proposed Heavy Duty Handhole
	Proposed Detector Loop
	Proposed Conduit: "T" Trench, "P" Push, Size Specified

DRAWN BY CADD
CHECKED BY

[illegible]

DATE _____

SCALE:	SHEET	OF	SHEETS	STA.	TO STA.
--------	-------	----	--------	------	---------

FAU RTE	SECTION	COUNTY	TOTAL SHEETS	SHEET NO.
8887	(122,122-1,30)RS-4	MADISON	328	261A
		CONTRACT NO. 76M87		
		ILLINOIS	FED. AID PROJECT	

ILLINOIS	FED. AID PROJECT
----------	------------------

```
MODEL: Default
ENGINE NAME: H-8066 IDOT Dist8 PTR 194 059,8066 010 W/O 11 150,DeslotID876M87-bdrf-AsBuiltplan.doc
```

HMG
ENGINEERS
PROF DESIGN FIRM 184.00

USER NAME	= nseelhoefer
PLOT SCALE	= 0.1667 ' / in
PLOT DATE	= 6/30/2022

DESIGNED	-
DRAWN	-
CHECKED	-
DATE	-

REVISED	-
REVISED	-
REVISED	-
REVISED	-


STATE OF ILLINOIS
DEPARTMENT OF TRANSPORTATION

IL ROUTE 159 & MAIN STREET

SCALE:	SHEET	OF	SHEETS	STA.	TO STA.
--------	-------	----	--------	------	---------

FAU RTE	SECTION	COUNTY	TOTAL SHEETS	SHEET NO.
8887	(122,122-1,30)RS-4	MADISON	328	261A
		CONTRACT NO. 76M87		
		ILLINOIS	FED. AID PROJECT	

ILLINOIS	FED. AID PROJECT
----------	------------------

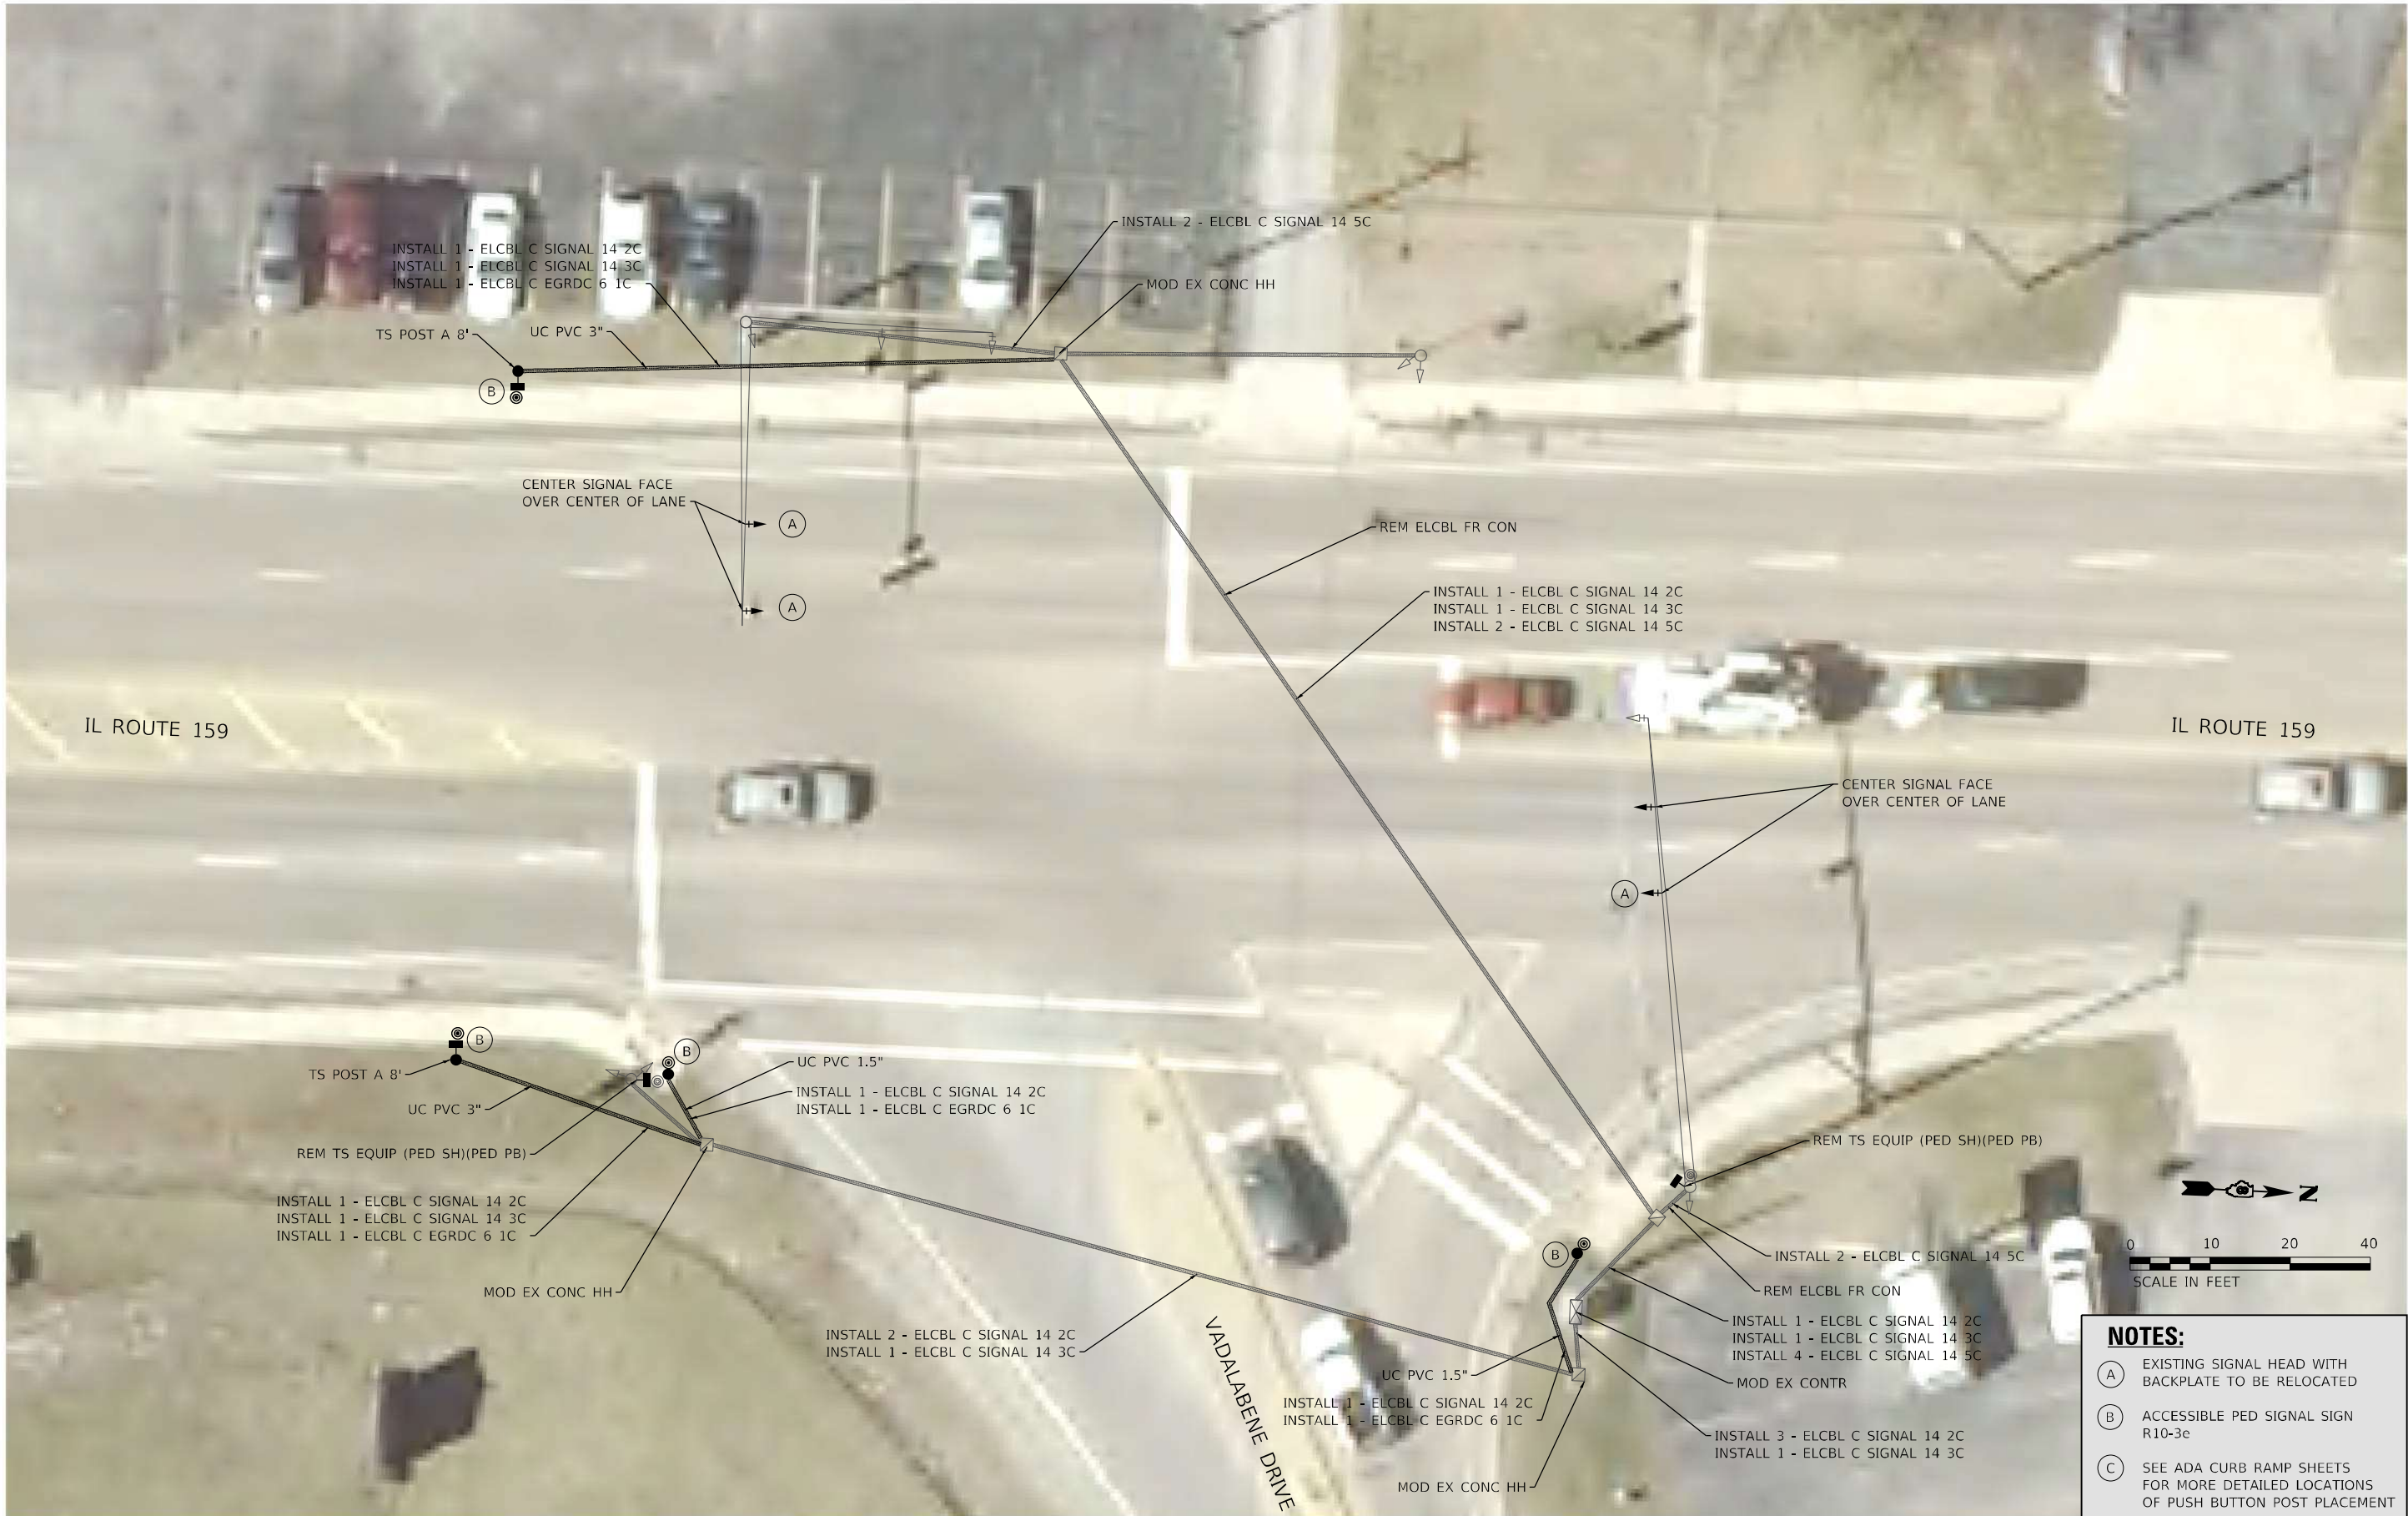

- NOTES:**
- (A) EXISTING SIGNAL HEAD WITH BACKPLATE TO BE RELOCATED
 - (B) ACCESSIBLE PED SIGNAL SIGN R10-3e
 - (C) SEE ADA CURB RAMP SHEETS FOR MORE DETAILED LOCATIONS OF PUSH BUTTON POST PLACEMENT

MODEL: Sheet 9 - Vadalabene
FILE NAME: 108249_019_159_Traffic_Signal_Upgrade_Coord_Sheets(0876M87).dgn

HMG
ENGINEERS
IL PROF DESIGN FIRM 184,000899

USER NAME	= nseelhoefer	DESIGNED	-	REVISED	-
		DRAWN	-	REVISED	-
PLOT SCALE	= 20,0000 ' / in.	CHECKED	-	REVISED	-
PLOT DATE	= 6/30/2022	DATE	-	REVISED	-

STATE OF ILLINOIS
DEPARTMENT OF TRANSPORTATION

TRAFFIC SIGNAL PLANS			
IL ROUTE 159 & VADALABENE DRIVE			
SCALE: 1" = 10'	SHEET TS 9 OF 31 SHEETS	STA.	TO STA.

F.A.P. RTE.	SECTION	COUNTY	TOTAL SHEETS	SHEET NO.
600	(122,122-1,30)RS-4	MADISON	328	262
CONTRACT NO. 76M87				
ILLINOIS FED. AID PROJECT				

MODEL: Sheet 24 - Vadalabene.dgn
FILE NAME: 108249_019_239_0218249_010.WD1_IL159_Traffic_Signal_Upgrade\Card_Sheets\0876M87-Cable_Diagram.dgn



USER NAME	= nseelhoefer
PLOT SCALE	= 10,0000 ' / in.
PLOT DATE	= 6/30/2022


DESIGNED	-
DRAWN	-
CHECKED	-
DATE	-

REVISED	-
REVISED	-
REVISED	-
REVISED	-




STATE OF ILLINOIS
DEPARTMENT OF TRANSPORTATION

CABLE DIAGRAM IL ROUTE 159 & VADALABENE DRIVE			
SCALE: NTS	SHEET TS 24 OF 31 SHEETS	STA.	TO STA.

F.A.P. RTE.	SECTION	COUNTY	TOTAL SHEETS	SHEET NO.
600	(122,122-1,30)RS-4	MADISON	328	263
CONTRACT NO. 76M87				
ILLINOIS FED. AID PROJECT				

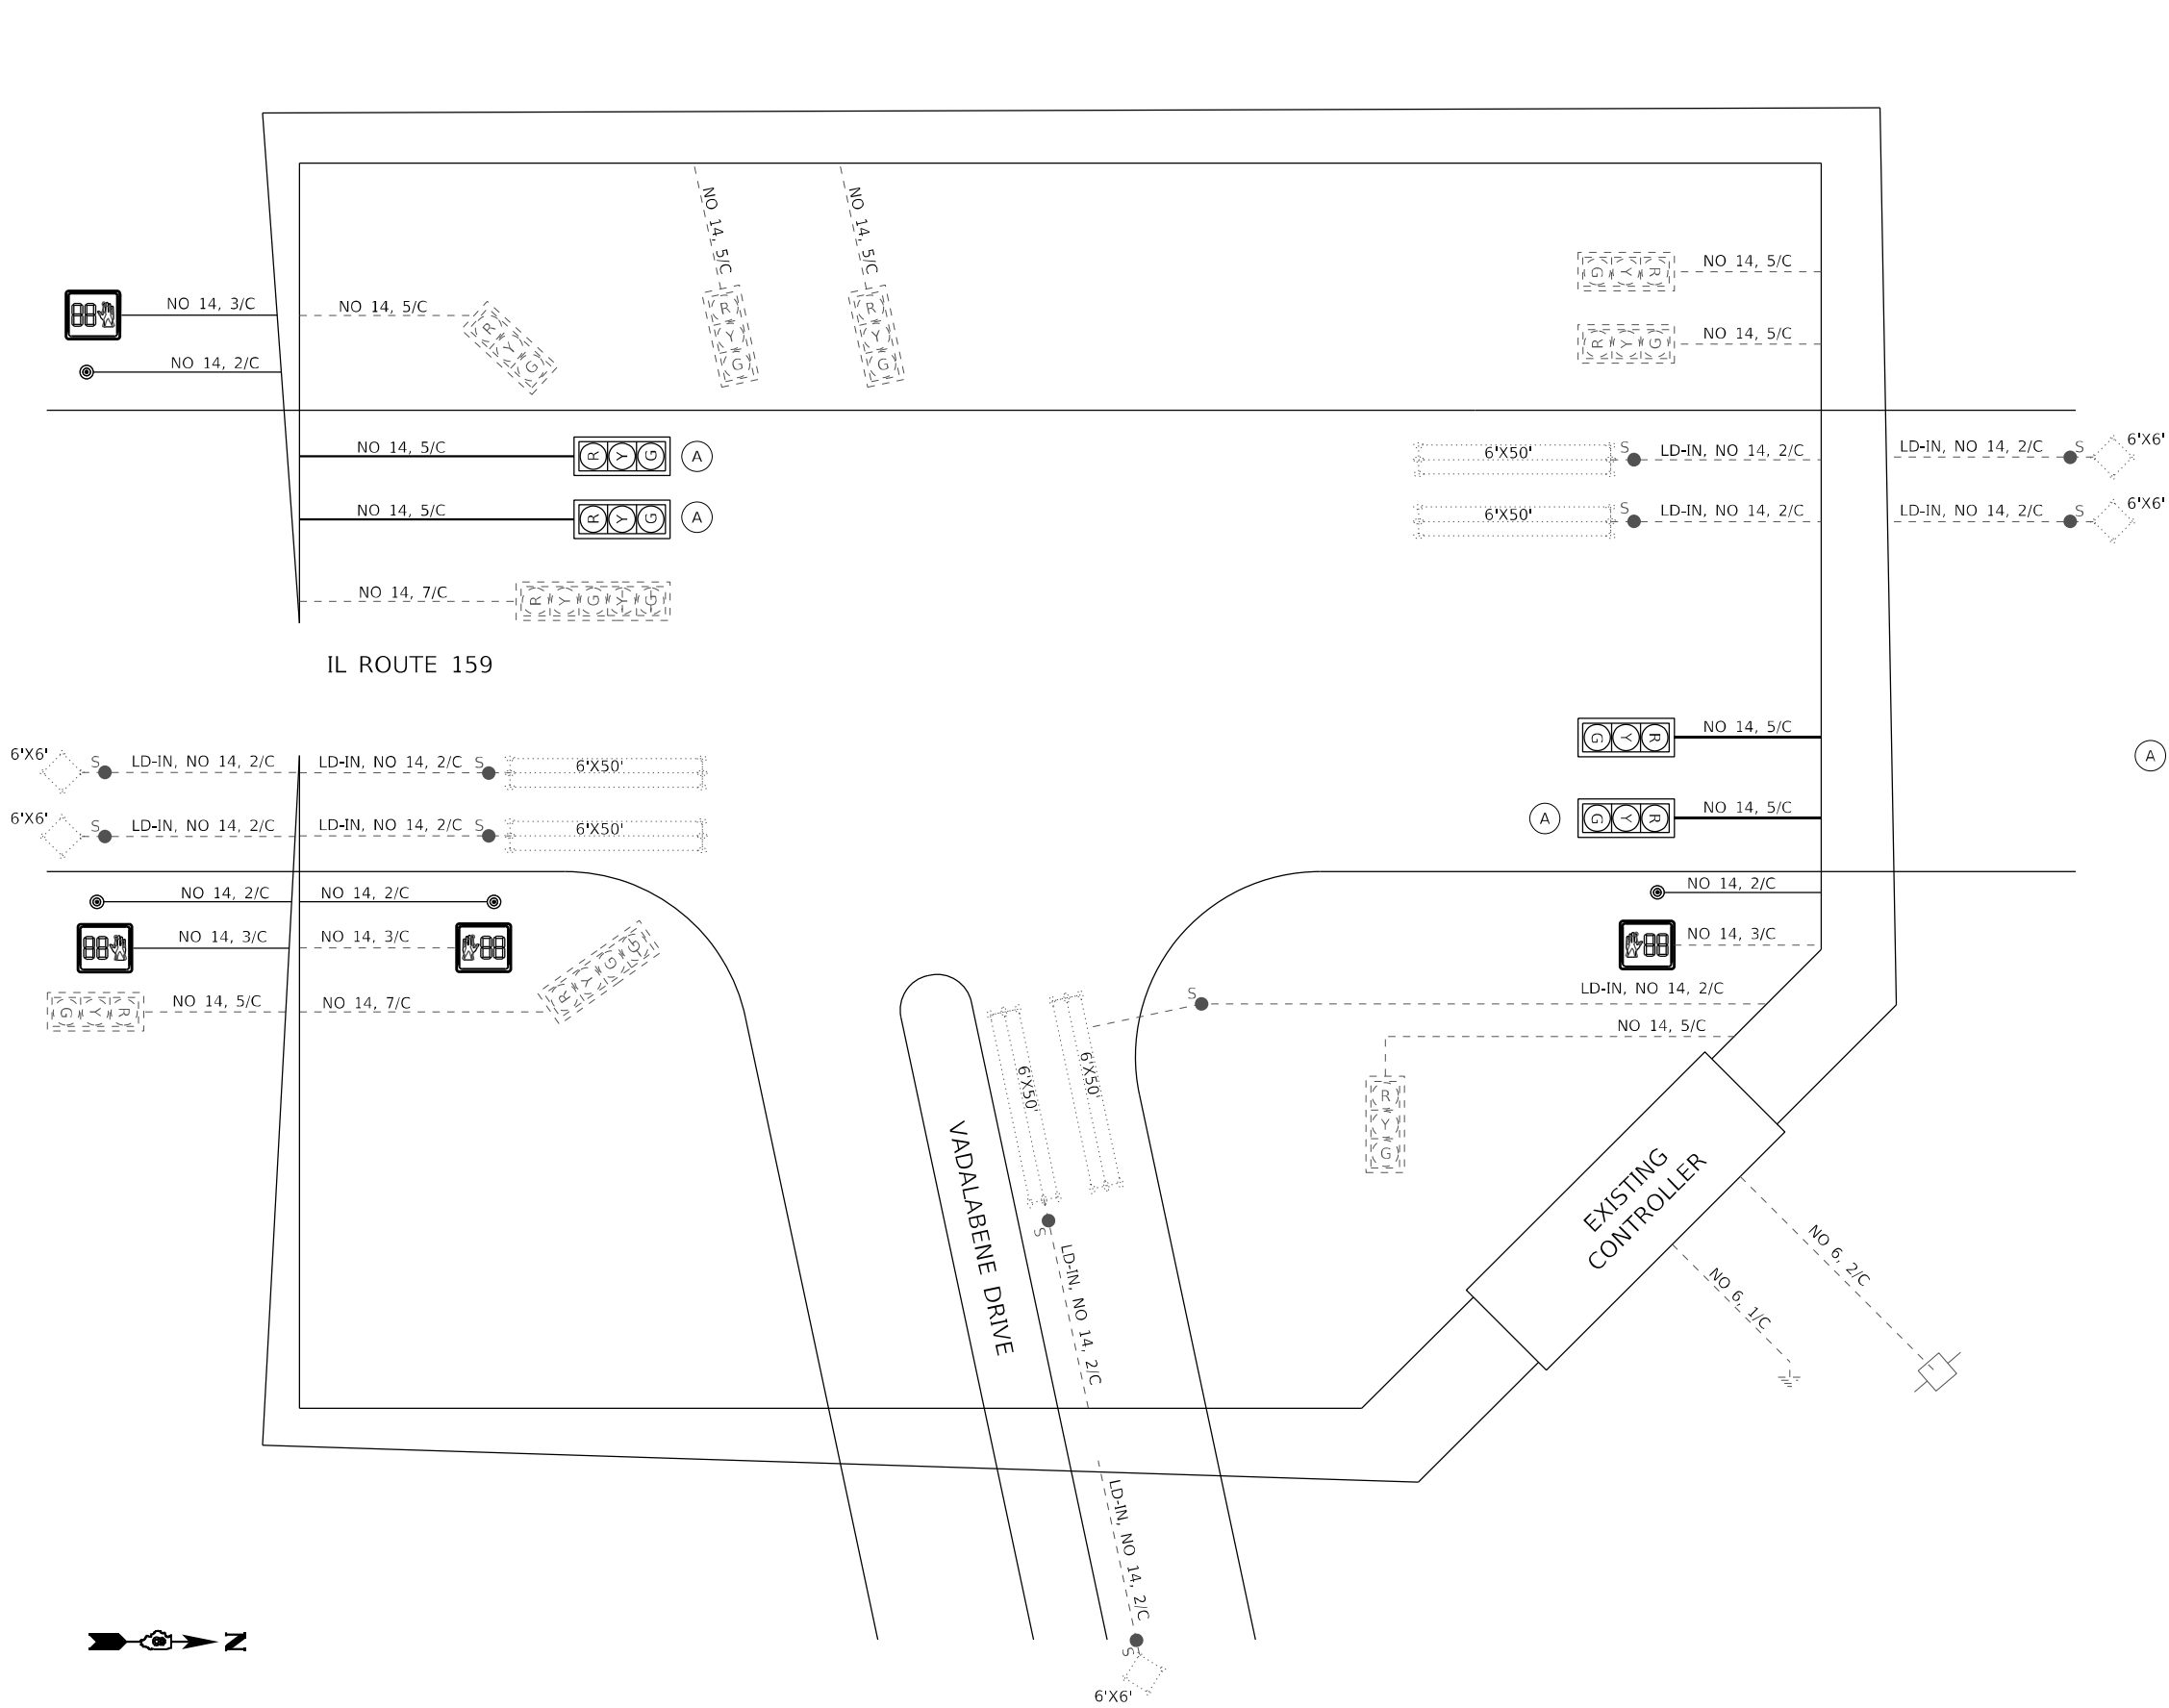

EXISTING TRAFFIC SIGNAL FACES

  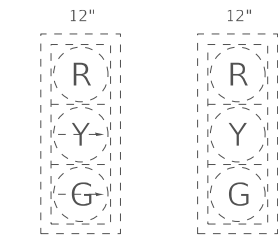

PEDESTRIAN PUSH BUTTON
WITH COUNTDOWN TIMER


PROPOSED TRAFFIC SIGNAL FACES

(A) EXISTING SIGNAL HEAD AND BACK PLATE TO BE RELOCATED



CABLE DIAGRAM LEGEND

- PROPOSED PEDESTRIAN PUSH BUTTON
- PROPOSED ELECTRIC CABLE IN CONDUIT
- INDICATES NUMBER OF CONDUCTORS IN CABLE
- NO. 6 INDICATES AMERICAN WIRE (AWG) SIZE 6
- EXISTING ELECTRIC CABLE IN CONDUIT
- EXISTING PEDESTRIAN PUSH BUTTON
- EXISTING SERVICE INSTALLATION
- CABLE SPLICE



FAP ROUTE	SECTION	COUNTY	TOTAL SHEETS	SHEET NO.
600	127-3R-3	MADISON	377	240
STA.		TO STA.		
EXISTING CONDITIONS:				

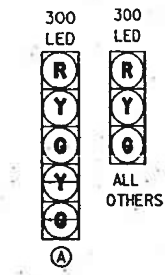

PROPOSED TRAFFIC SIGNAL FACES

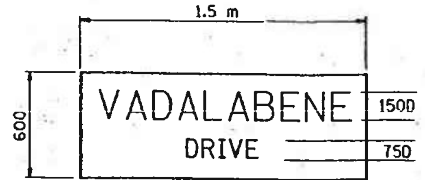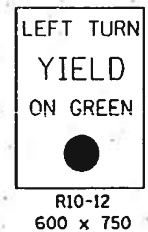


STREET NAME SIGN
DETAIL E
NOT TO SCALE

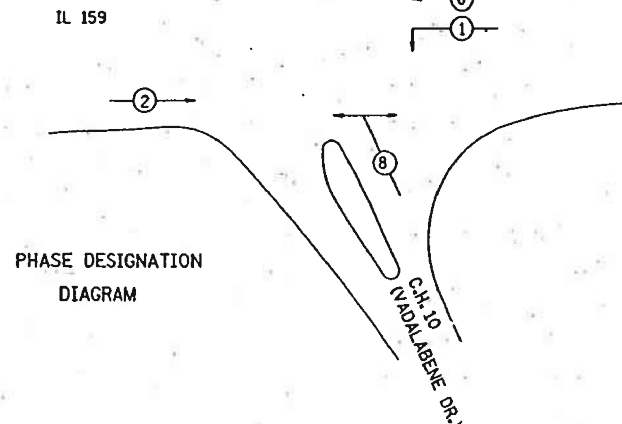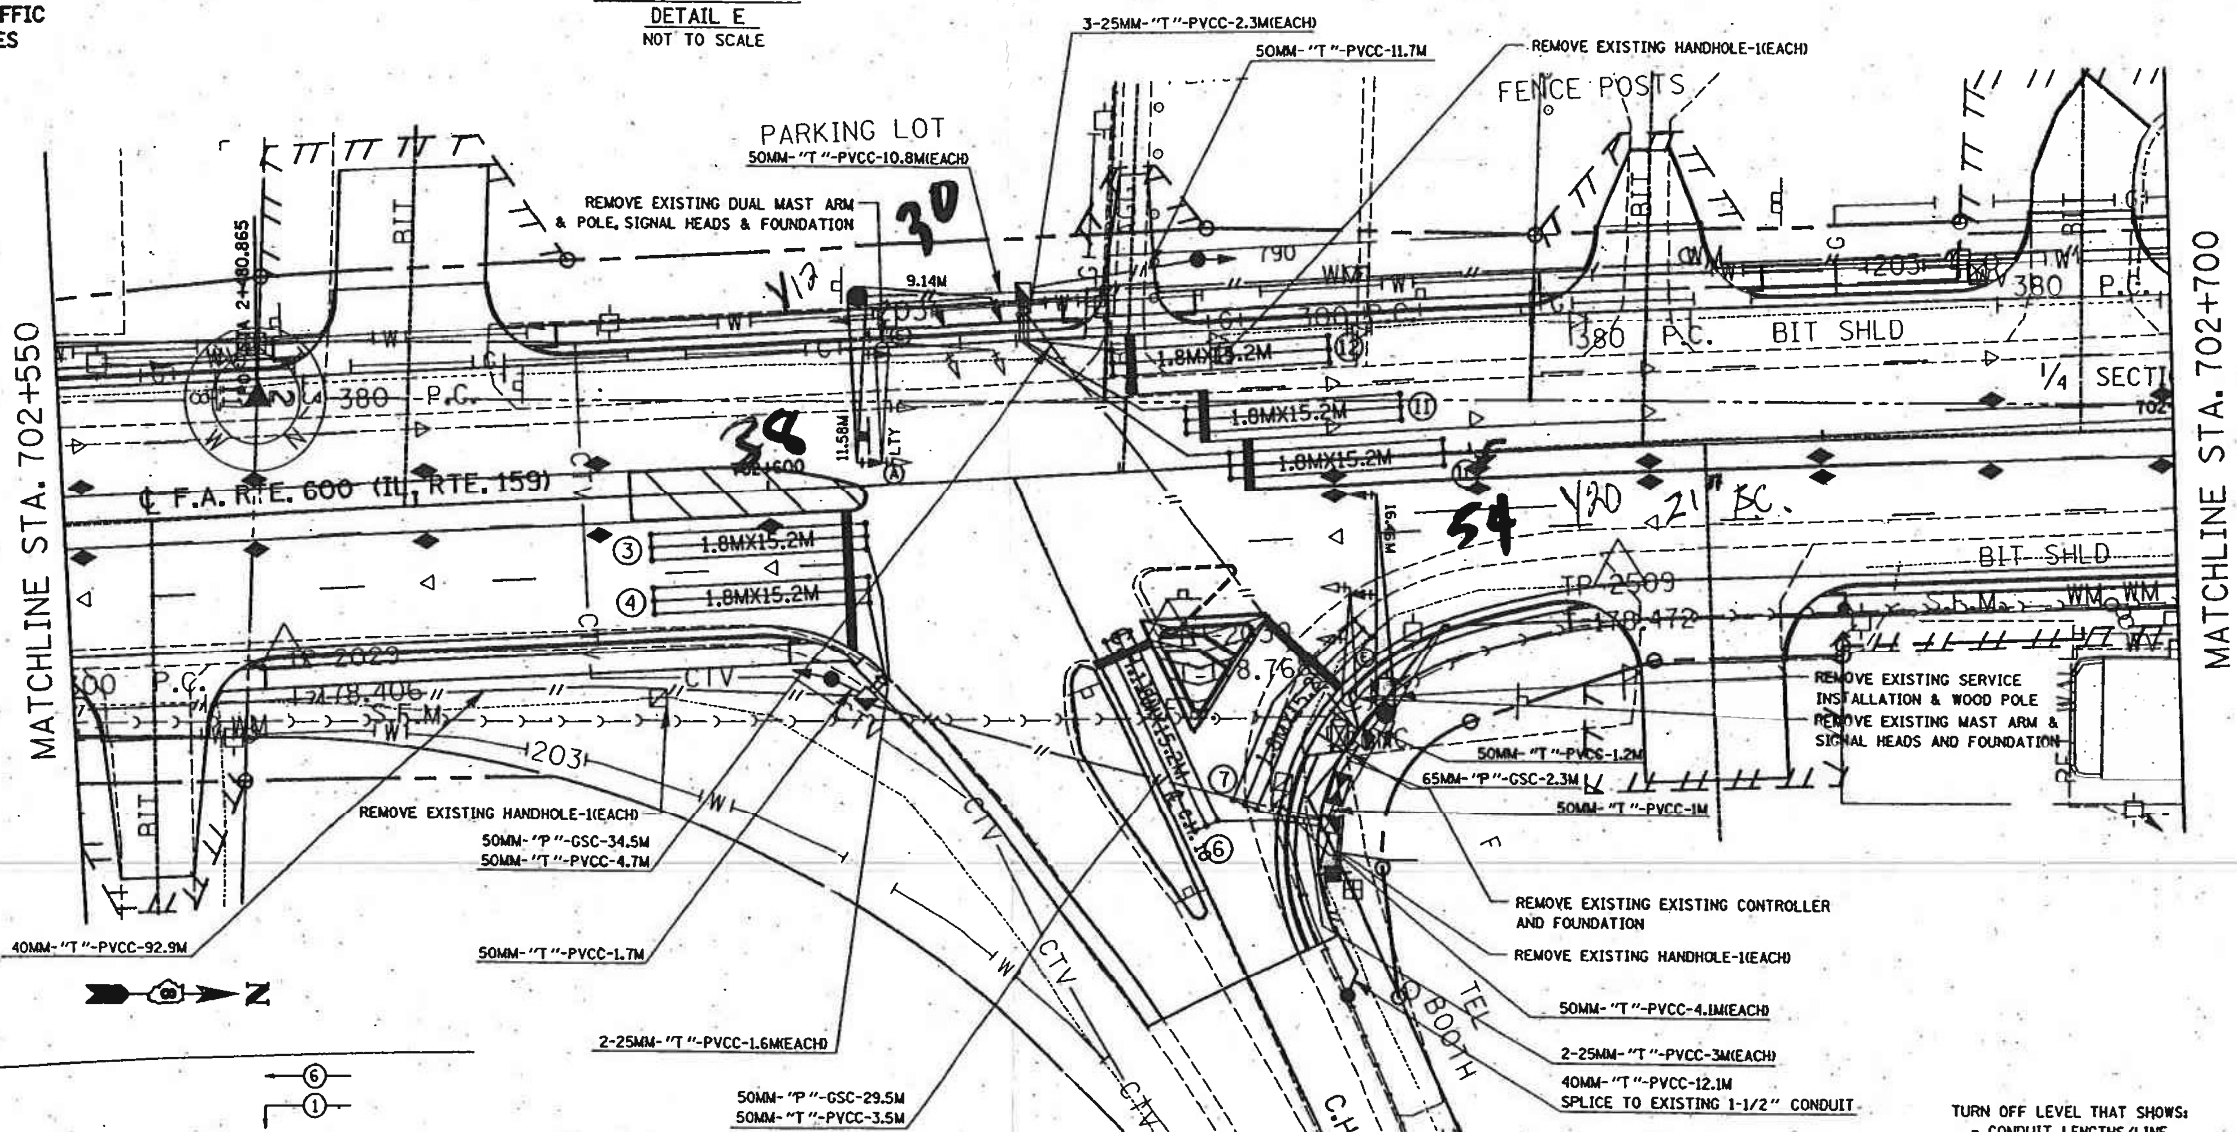

FULL-ACTUATED CONTROLLER IN TYPE IV CABINET

	PROPOSED SEQUENCE OF OPERATION							
PHASE	1	2	3	4	5	6	7	8
MOVEMENT	SBLT	NB	NOT	NOT	NOT	SB	NOT	TWB
CONCURRENT MOVEMENT PERMITTED	6	6	USED	USED	USED	2	USED	NONE

 - TURN OFF LEVEL THAT SHOWS:
- CONDUIT LENGTHS/LINE
 - DET. LOOP LEAD-IN LENGTHS/LINE
 - MAST ARM MOUNTED SIGNAL HEAD LENGTHS/LINES
 - SHOW METRIC CONDUIT SIZES, ONLY TYPICAL EACH SHEET
 - HAND HOLE NUMBERS



ALL DIMENSIONS ARE IN mm UNLESS DESIGNATED OTHERWISE

REVISIONS	NAME	DATE

ILLINOIS DEPARTMENT OF TRANSPORTATION
IL 159 AND C.H. 10
TRAFFIC SIGNAL PLAN
 FAP 600 ROUTE
 SECTION 127-3R-3
 MADISON COUNTY
 DRAWN BY: 1 OF 2

MODEL: Default
 FILE NAME: 1030066_10DOT.DWG
 PLOT DATE: 6/30/2022




USER NAME	= nseelhoefer	DESIGNED	-	REVISED	-
PLOT SCALE	= 0.1667" / 1m	DRAWN	-	REVISED	-
PLOT DATE	= 6/30/2022	CHECKED	-	REVISED	-
		DATE	-	REVISED	-

STATE OF ILLINOIS
DEPARTMENT OF TRANSPORTATION

AS BUILTS
IL ROUTE 159 & VADALABENE DRIVE

SCALE: SHEET OF SHEETS STA. TO STA.

FAP ROUTE	SECTION	COUNTY	TOTAL SHEETS	SHEET NO.
8887	(122,122-1,30)RS-4	MADISON	328	263A
CONTRACT NO. 76M87				
ILLINOIS FED. AID PROJECT				

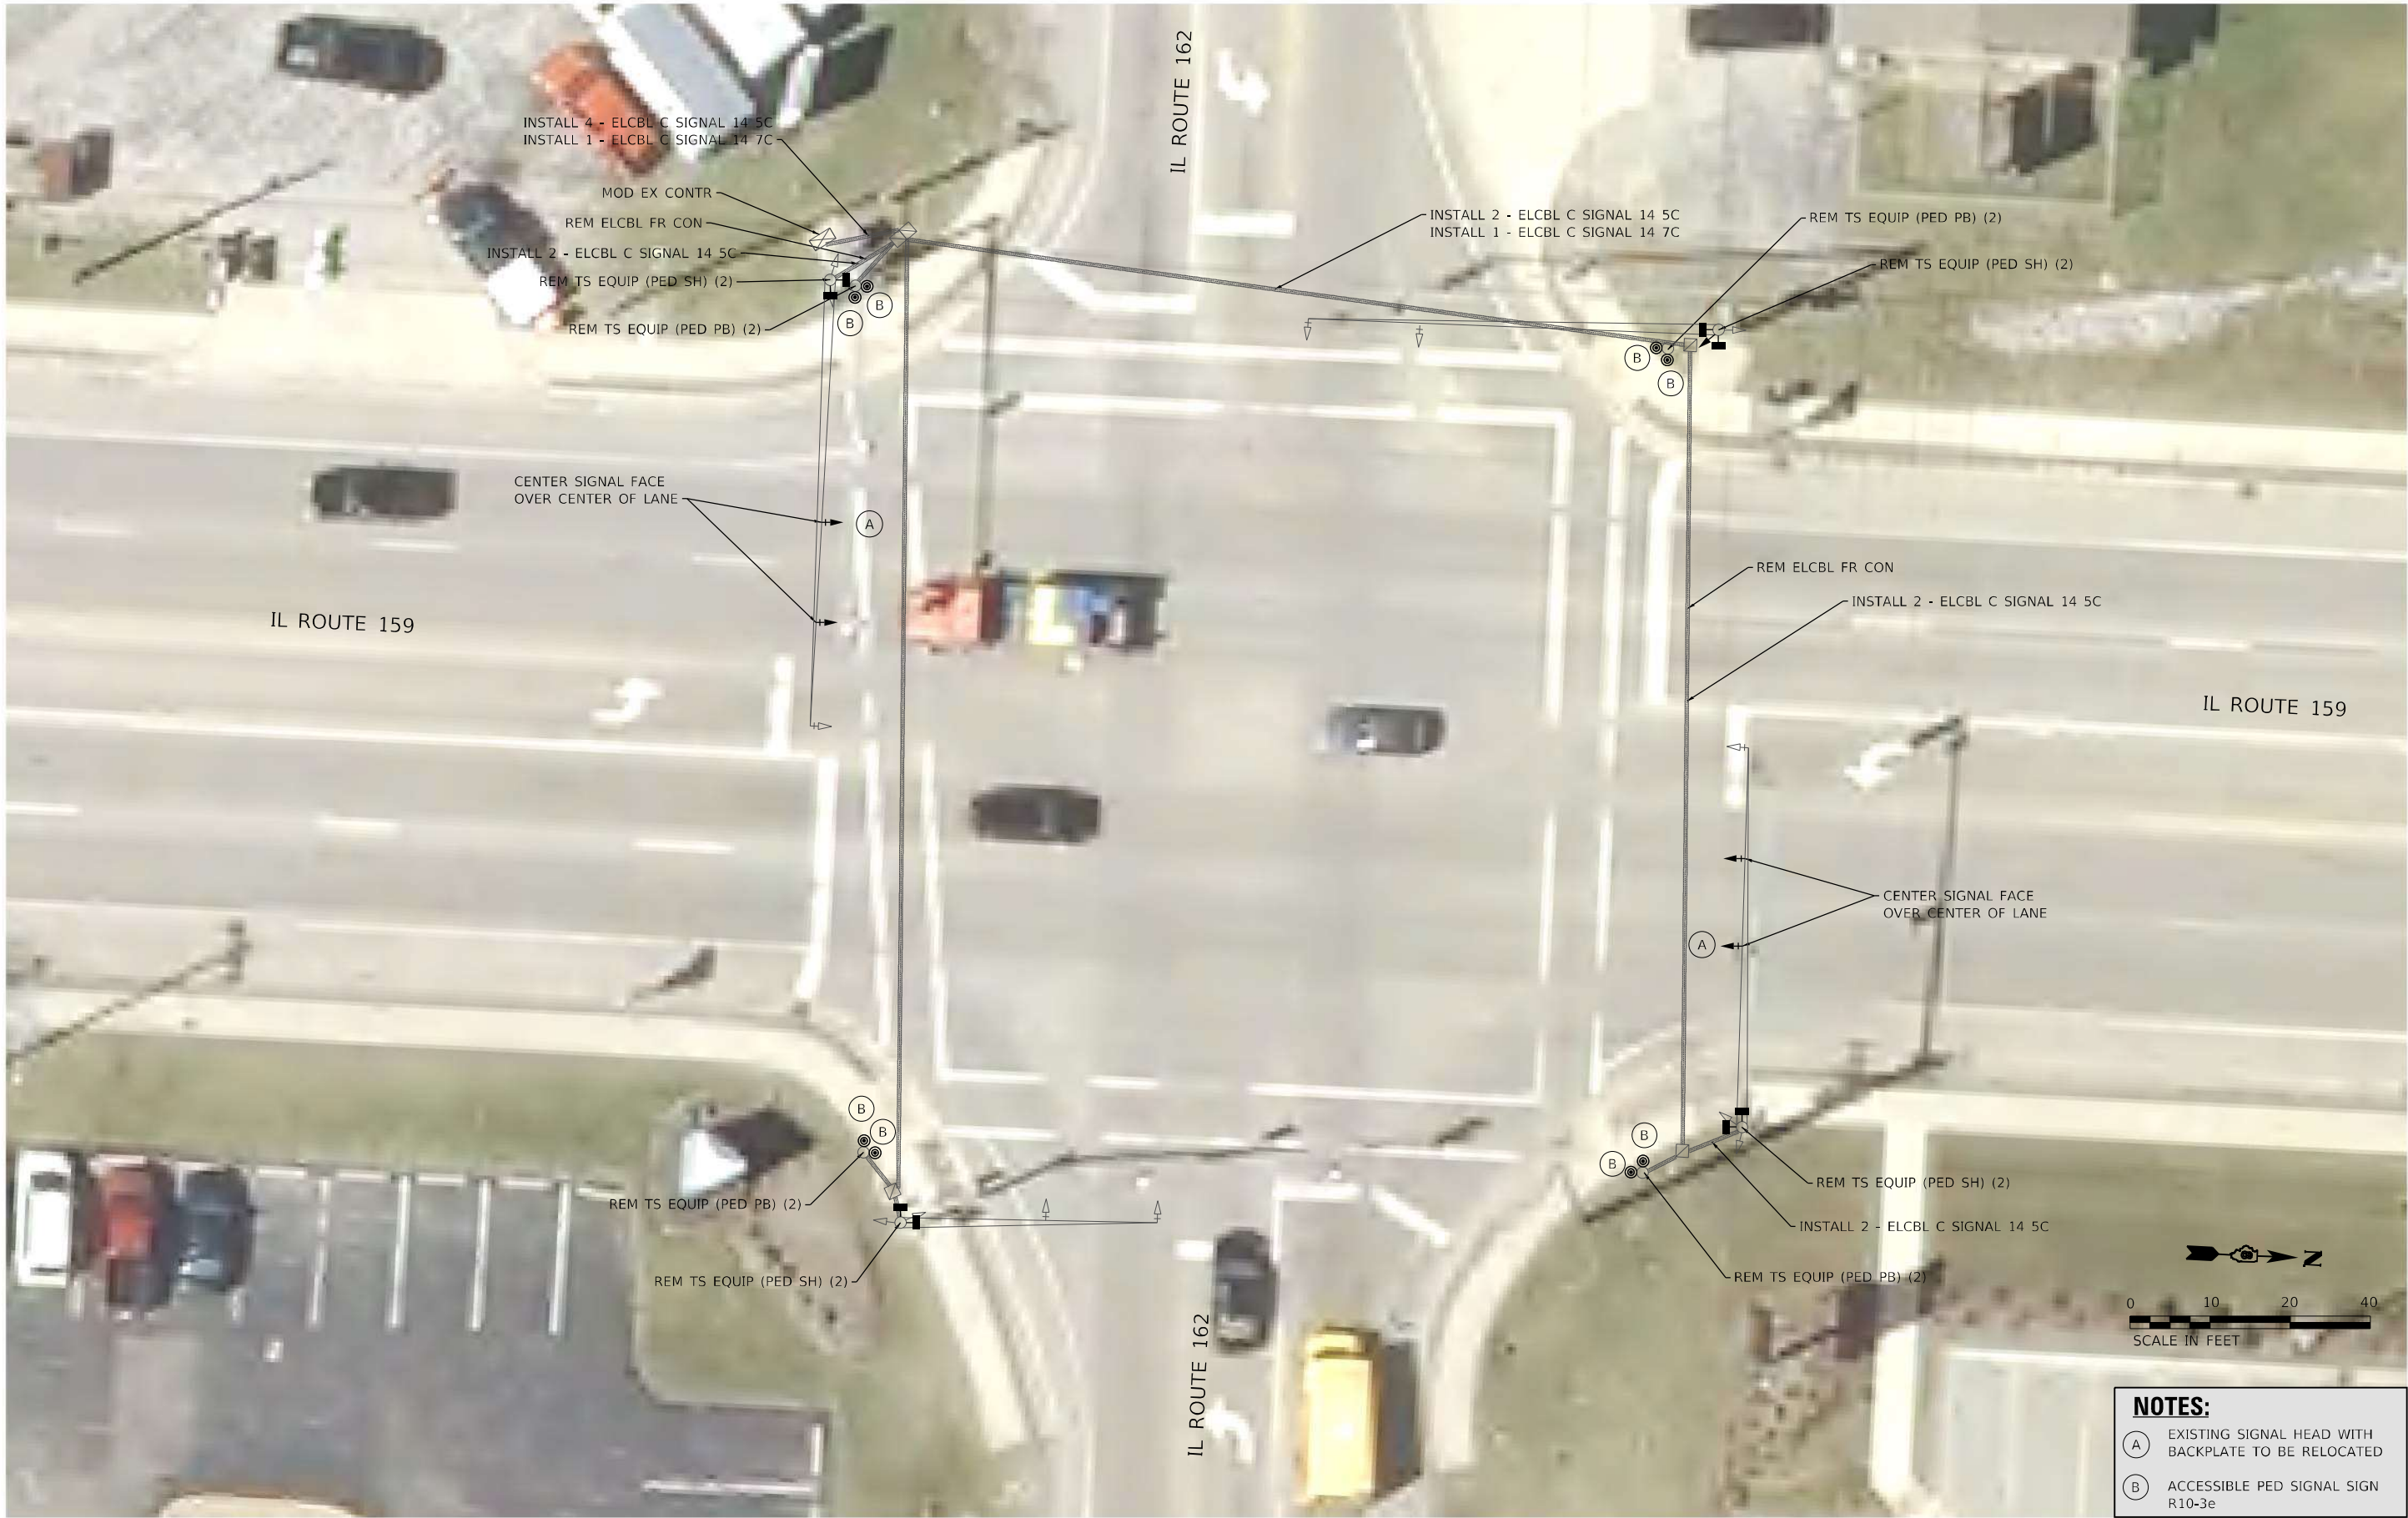

- NOTES:**
- (A) EXISTING SIGNAL HEAD WITH BACKPLATE TO BE RELOCATED
 - (B) ACCESSIBLE PED SIGNAL SIGN R10-3e

MODEL: Sheet 10 - IL 162
FILE NAME: 108294_775_159_0218219_010_W01_IL159_Traffic_Signal_Upgrade.dgn

HMG
ENGINEERS
IL PROF DESIGN FIRM 184,000899

USER NAME = nseelhoefer	DESIGNED -	REVISED -
PLOT SCALE = 20,000' / in.	DRAWN -	REVISED -
PLOT DATE = 6/30/2022	CHECKED -	REVISED -
	DATE -	REVISED -

STATE OF ILLINOIS
DEPARTMENT OF TRANSPORTATION

TRAFFIC SIGNAL PLANS			
IL ROUTE 159 & IL ROUTE 162			
SCALE: 1" = 10'	SHEET TS 10 OF 31 SHEETS	STA.	TO STA.

F.A.P. RTE.	SECTION	COUNTY	TOTAL SHEETS	SHEET NO.
600	(122,122-1,30)RS-4	MADISON	328	264
CONTRACT NO. 76M87				
ILLINOIS FED. AID PROJECT				

MODEL: Sheet 25 - IL RTE 162
FILE NAME: 1082249_7705_159_0218249_010.WD1_IL159_Traffic_Signal_Upgrade\Card_Sheets\0876M87-Cable_Diagram.dgn



USER NAME	= nseelhoefer
PLOT SCALE	= 10,0000 ' / in.
PLOT DATE	= 6/30/2022

DESIGNED -	
DRAWN -	
CHECKED -	
DATE -	


REVISED -	
REVISED -	
REVISED -	
REVISED -	

STATE OF ILLINOIS
DEPARTMENT OF TRANSPORTATION


CABLE DIAGRAM
IL ROUTE 159 & IL ROUTE 162

SCALE: NTS SHEET TS 25 OF 31 SHEETS STA. TO STA.

F.A.P. RTE.	SECTION	COUNTY	TOTAL SHEETS	SHEET NO.
600	(122,122-1,30)RS-4	MADISON	328	265
CONTRACT NO. 76M87				
ILLINOIS FED. AID PROJECT				

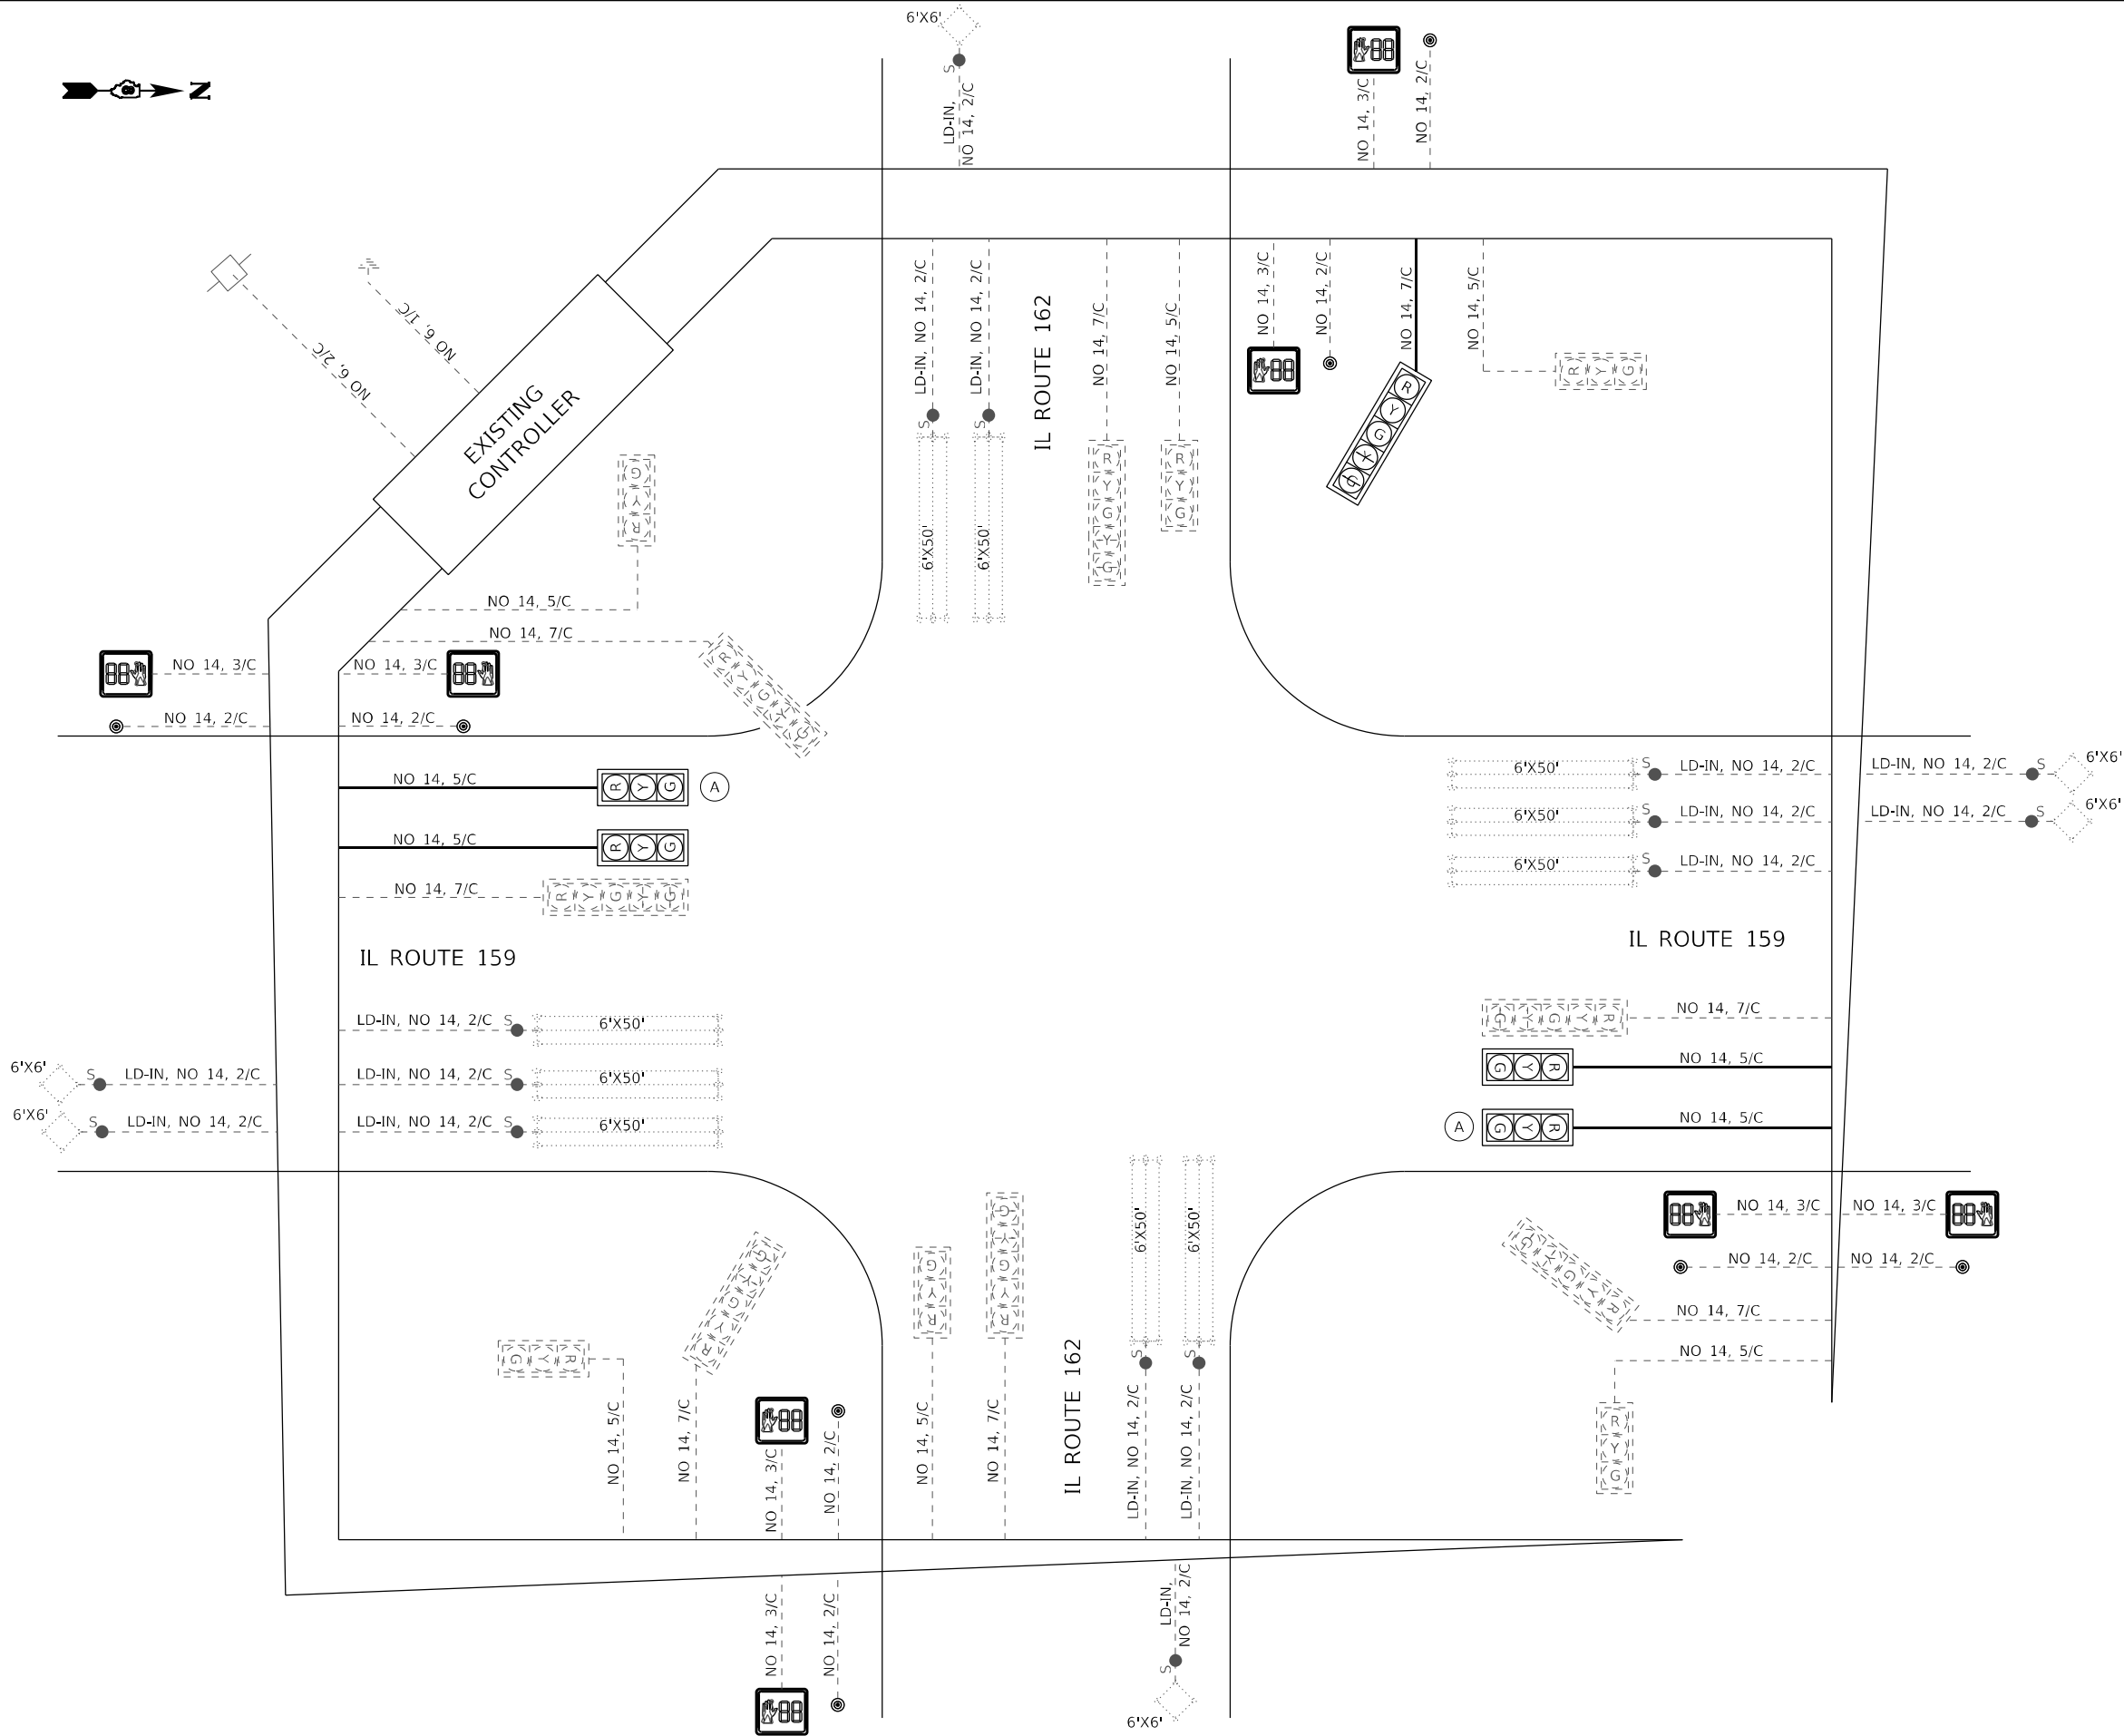

EXISTING TRAFFIC SIGNAL FACES

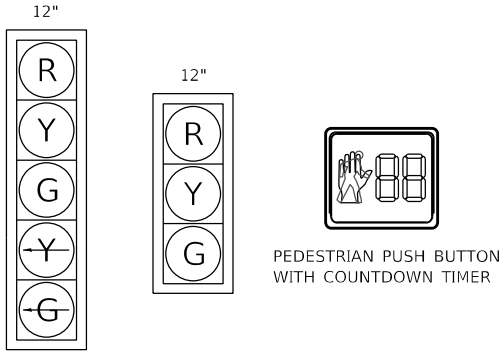

PROPOSED TRAFFIC SIGNAL FACES

(A) EXISTING SIGNAL HEAD AND BACK PLATE TO BE RELOCATED

CABLE DIAGRAM LEGEND

- PROPOSED PEDESTRIAN PUSH BUTTON
- PROPOSED ELECTRIC CABLE IN CONDUIT
- INDICATES NUMBER OF CONDUCTORS IN CABLE
- INDICATES AMERICAN WIRE (AWG) SIZE 6
- EXISTING ELECTRIC CABLE IN CONDUIT
- EXISTING PEDESTRIAN PUSH BUTTON
- EXISTING SERVICE INSTALLATION
- CABLE SPLICE

SECTION	COUNTY	TOTAL SHEETS	SHEET NO.
127-2TS	MADISON	40	29
EXISTING CONDITIONS	STD. SURVEY		



NOTE: THE CONTRACTOR SHALL LAY CONDUIT IN THE TRENCH PRIOR TO THE IMPROVEMENT TO THE PRIVATE ENTRANCE AT STA. 365+93

NOTE: THE CONTRACTOR SHALL LAY CONDUIT IN THE TRENCH PRIOR TO THE IMPROVEMENT TO THE PRIVATE ENTRANCES AT STA. 369+88 AND STA. 371+50

PROPOSED TRAFFIC SIGNAL FACES

12" R Y G Y G

12" R Y G Y G

FULL-ACTUATED CONTROLLER, STANDARD SEQUENCE IV 8 PHASES, IN TYPE IV CABINET, SPECIAL

PROPOSED OPERATION							
PHASE	1	2	3	4	5	6	7
MOVEMENT	—	—	—	—	—	—	—
CONCURRENT MOVEMENT PERMITTED	5 OF 6	5 OF 6	7 OR 8	7 OR 8	1 OR 2	1 OR 2	3 OR 4

PHASE DESIGNATION DIAGRAM

ILL. ROUTE 162

ILL. ROUTE 159

ILL. ROUTE 162

STATE OF ILLINOIS
DEPARTMENT OF TRANSPORTATION

AS BUILT
IL ROUTE 159 & IL ROUTE 162

ILLINOIS DEPARTMENT OF TRANSPORTATION
TRAFFIC SIGNAL PLAN
FAP ROUTE 600
SECTION 127-2TS
MADISON COUNTY

DRAWN BY A.C.M.
CHECKED BY

DATE

REVISIONS	
NAME	DATE

20 0 20 40
SCALE: 1" = 20'

HMG
ENGINEERS
IL PROF DESIGN FIRM 184,000899


USER NAME = nseelhoefer
PLOT SCALE = 0.1667" / ft.
PLOT DATE = 6/30/2022

DESIGNED -
DRAWN -
CHECKED -
DATE -

REVISED -
REVISED -
REVISED -
REVISED -

SCALE: SHEET OF SHEETS STA. TO STA.

FAU RTE	SECTION	COUNTY	TOTAL SHEETS	SHEET NO.
8887	(122,122-1,30)RS-4	MADISON	328	265A
CONTRACT NO. 76M87				
ILLINOIS FED. AID PROJECT				

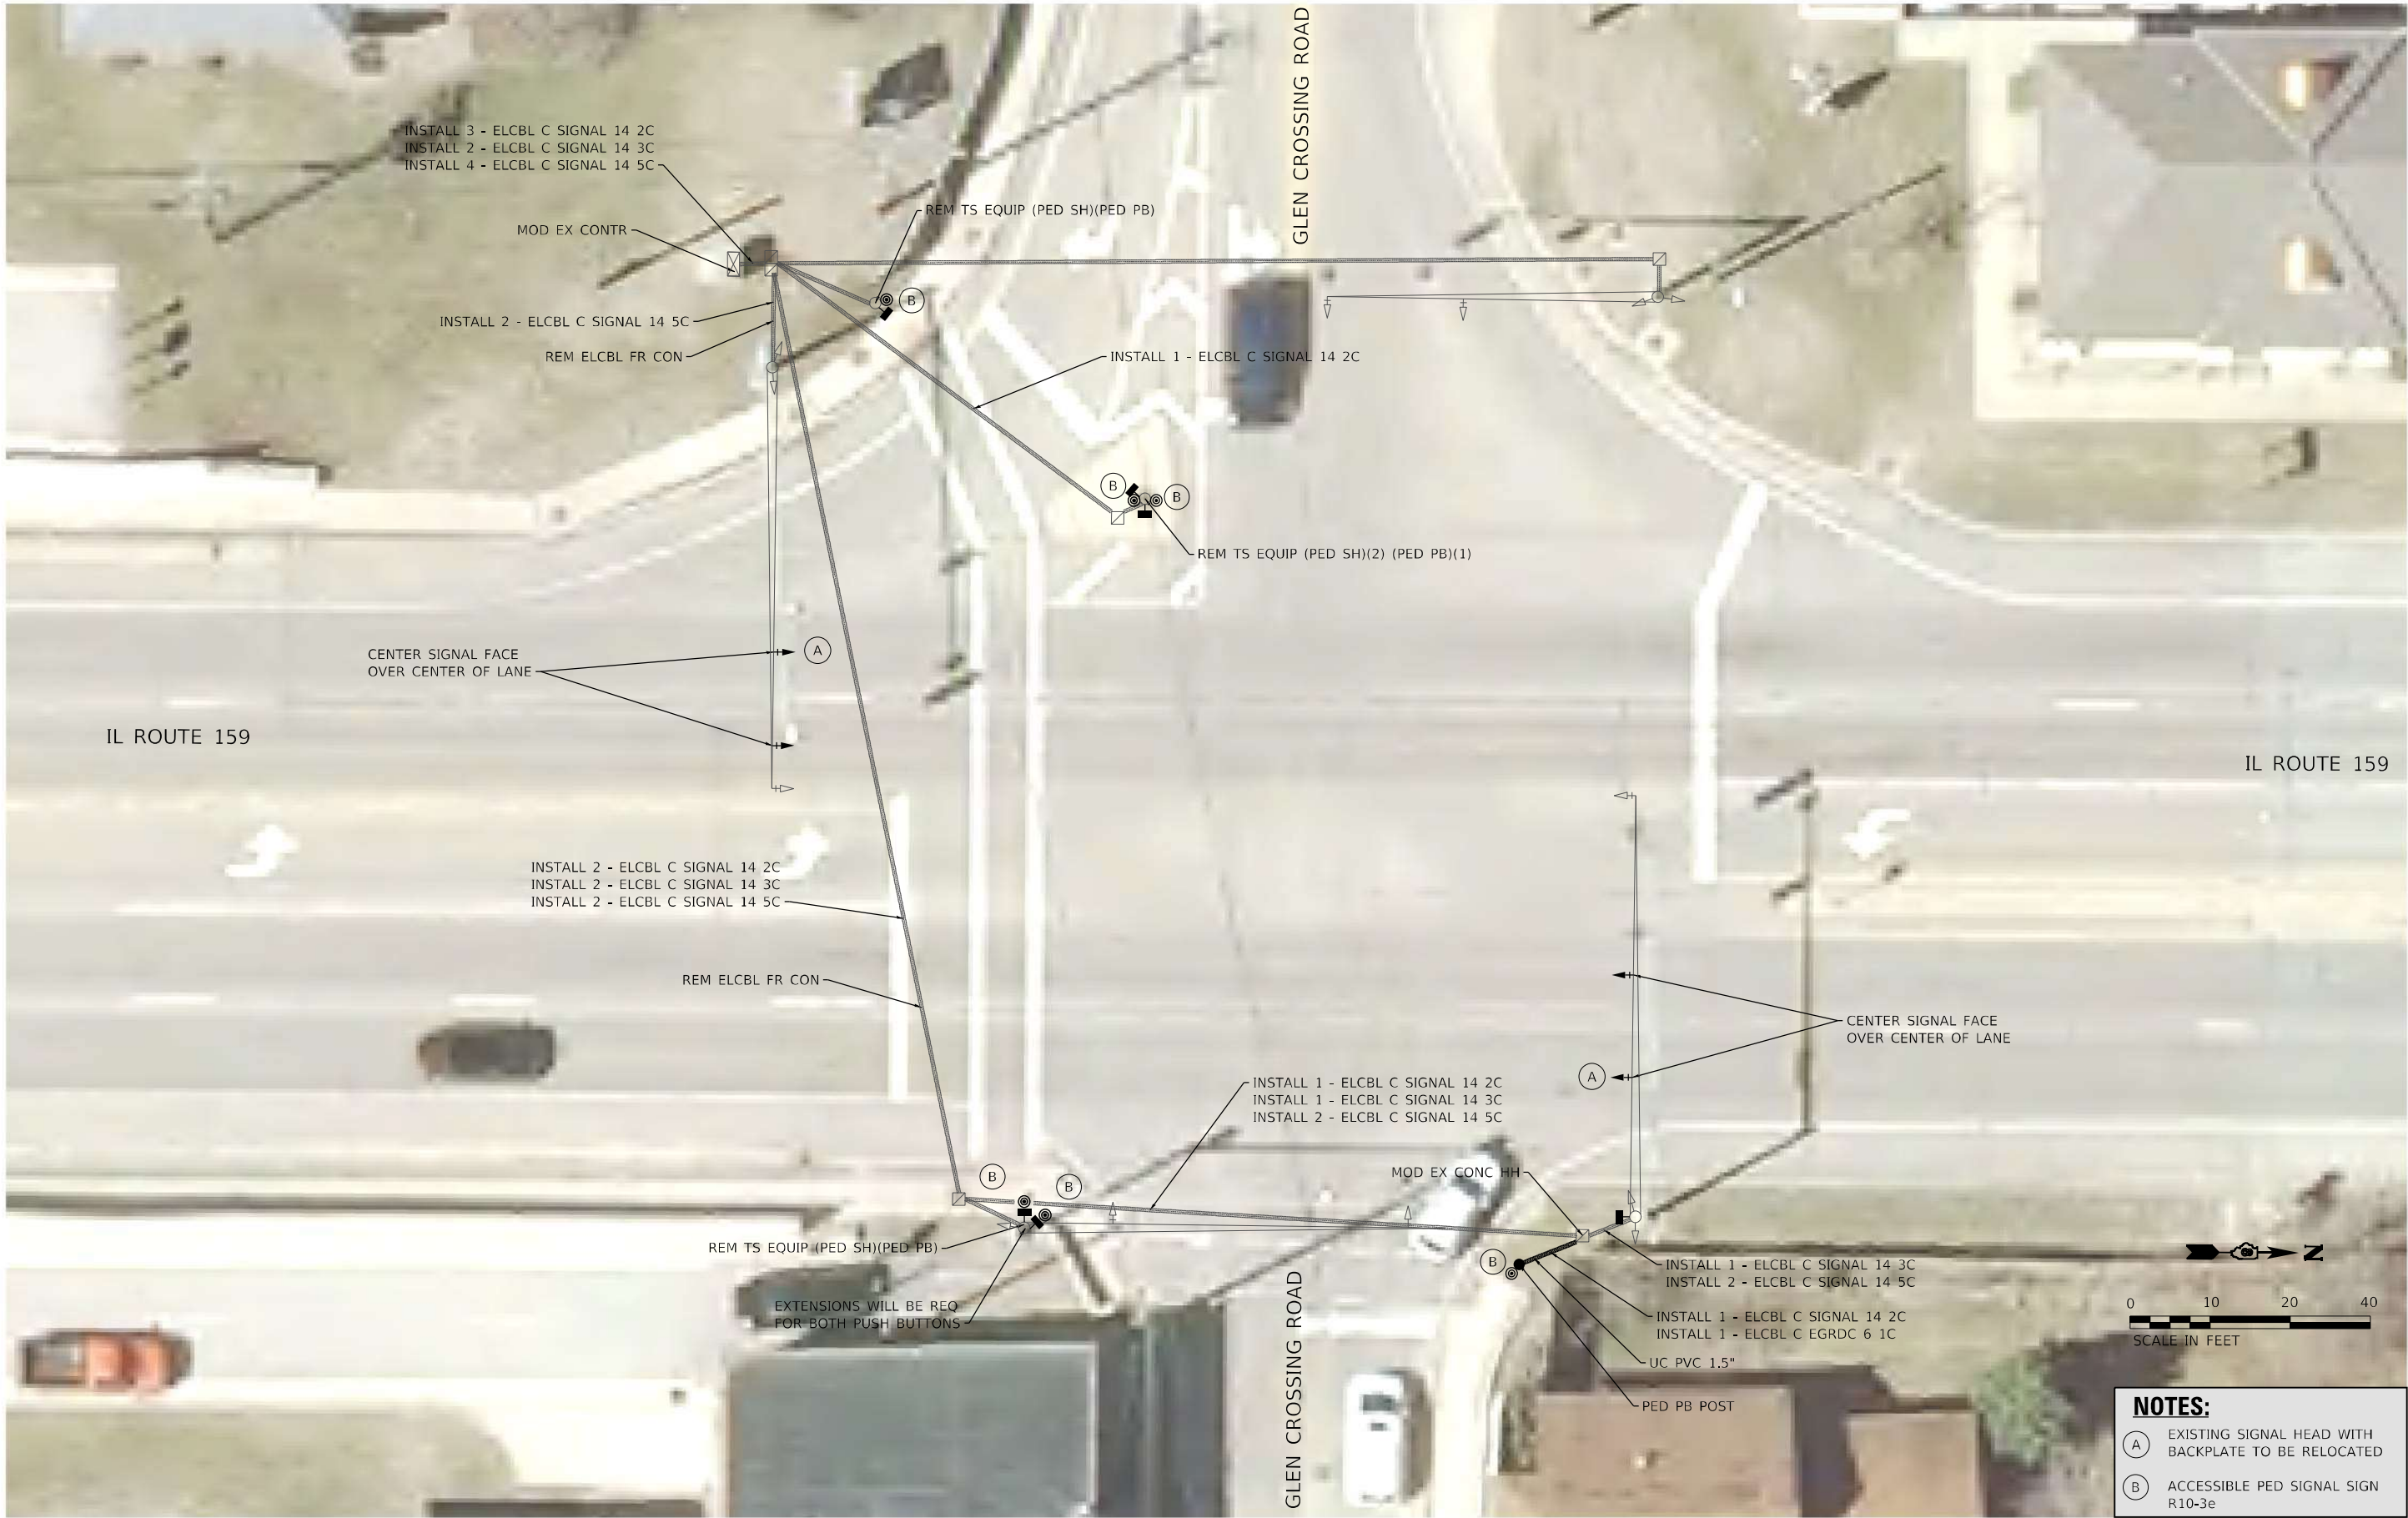

- NOTES:**
- (A) EXISTING SIGNAL HEAD WITH BACKPLATE TO BE RELOCATED
 - (B) ACCESSIBLE PED SIGNAL SIGN R10-3e

MODEL: Sheet 11 - Glen Crossing
FILE NAME: 108249_019_159_022020219_010_W01_IL159_Traffic_Signal_UpgradeCard_Sheets(0876M87-1).dgn

HMG
ENGINEERS
IL PROF DESIGN FIRM 184,000899

USER NAME	= nseelhoefer	DESIGNED -	REVISED -
		DRAWN -	REVISED -
PLOT SCALE	= 20,0000 ' / in.	CHECKED -	REVISED -
PLOT DATE	= 6/30/2022	DATE -	REVISED -

STATE OF ILLINOIS
DEPARTMENT OF TRANSPORTATION

TRAFFIC SIGNAL PLANS
IL ROUTE 159 & GLEN CROSSING ROAD

SCALE: 1" = 10' SHEET TS 11 OF 31 SHEETS STA. TO STA.

F.A.P. RTE.	SECTION	COUNTY	TOTAL SHEETS	SHEET NO.
600	(122,122-1,30)RS-4	MADISON	328	266
CONTRACT NO. 76M87				
ILLINOIS FED. AID PROJECT				

MODEL: Sheet 26 - Glen Crossing
FILE NAME: 1188249_010_159_2228249_010_W01_IL159_Traffic-Signal-Upgrade\Card-Sheets\1188249_010_W01_IL159_Traffic-Signal-Upgrade.dgn



USER NAME = bratermann
DESIGNED -
DRAWN -
PLOT SCALE = 10,0000' / in.
CHECKED -
PLOT DATE = 6/30/2022
DATE -



REVISD -
REVISD -
REVISD -
REVISD -

STATE OF ILLINOIS
DEPARTMENT OF TRANSPORTATION


CABLE DIAGRAM
IL ROUTE 159 & GLEN CROSSING ROAD

SCALE: NTS SHEET TS 26 OF 31 SHEETS STA. TO STA.

F.A.P. RTE.	SECTION	COUNTY	TOTAL SHEETS	SHEET NO.
600	(122,122-1,30)RS-4	MADISON	328	267
CONTRACT NO. 76M87				
ILLINOIS FED. AID PROJECT				

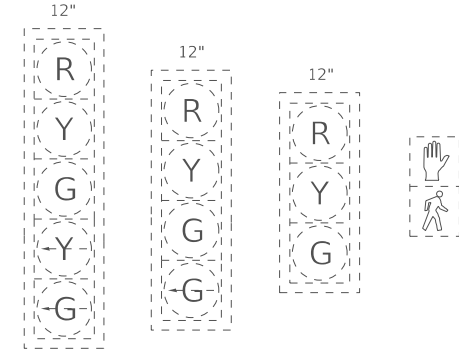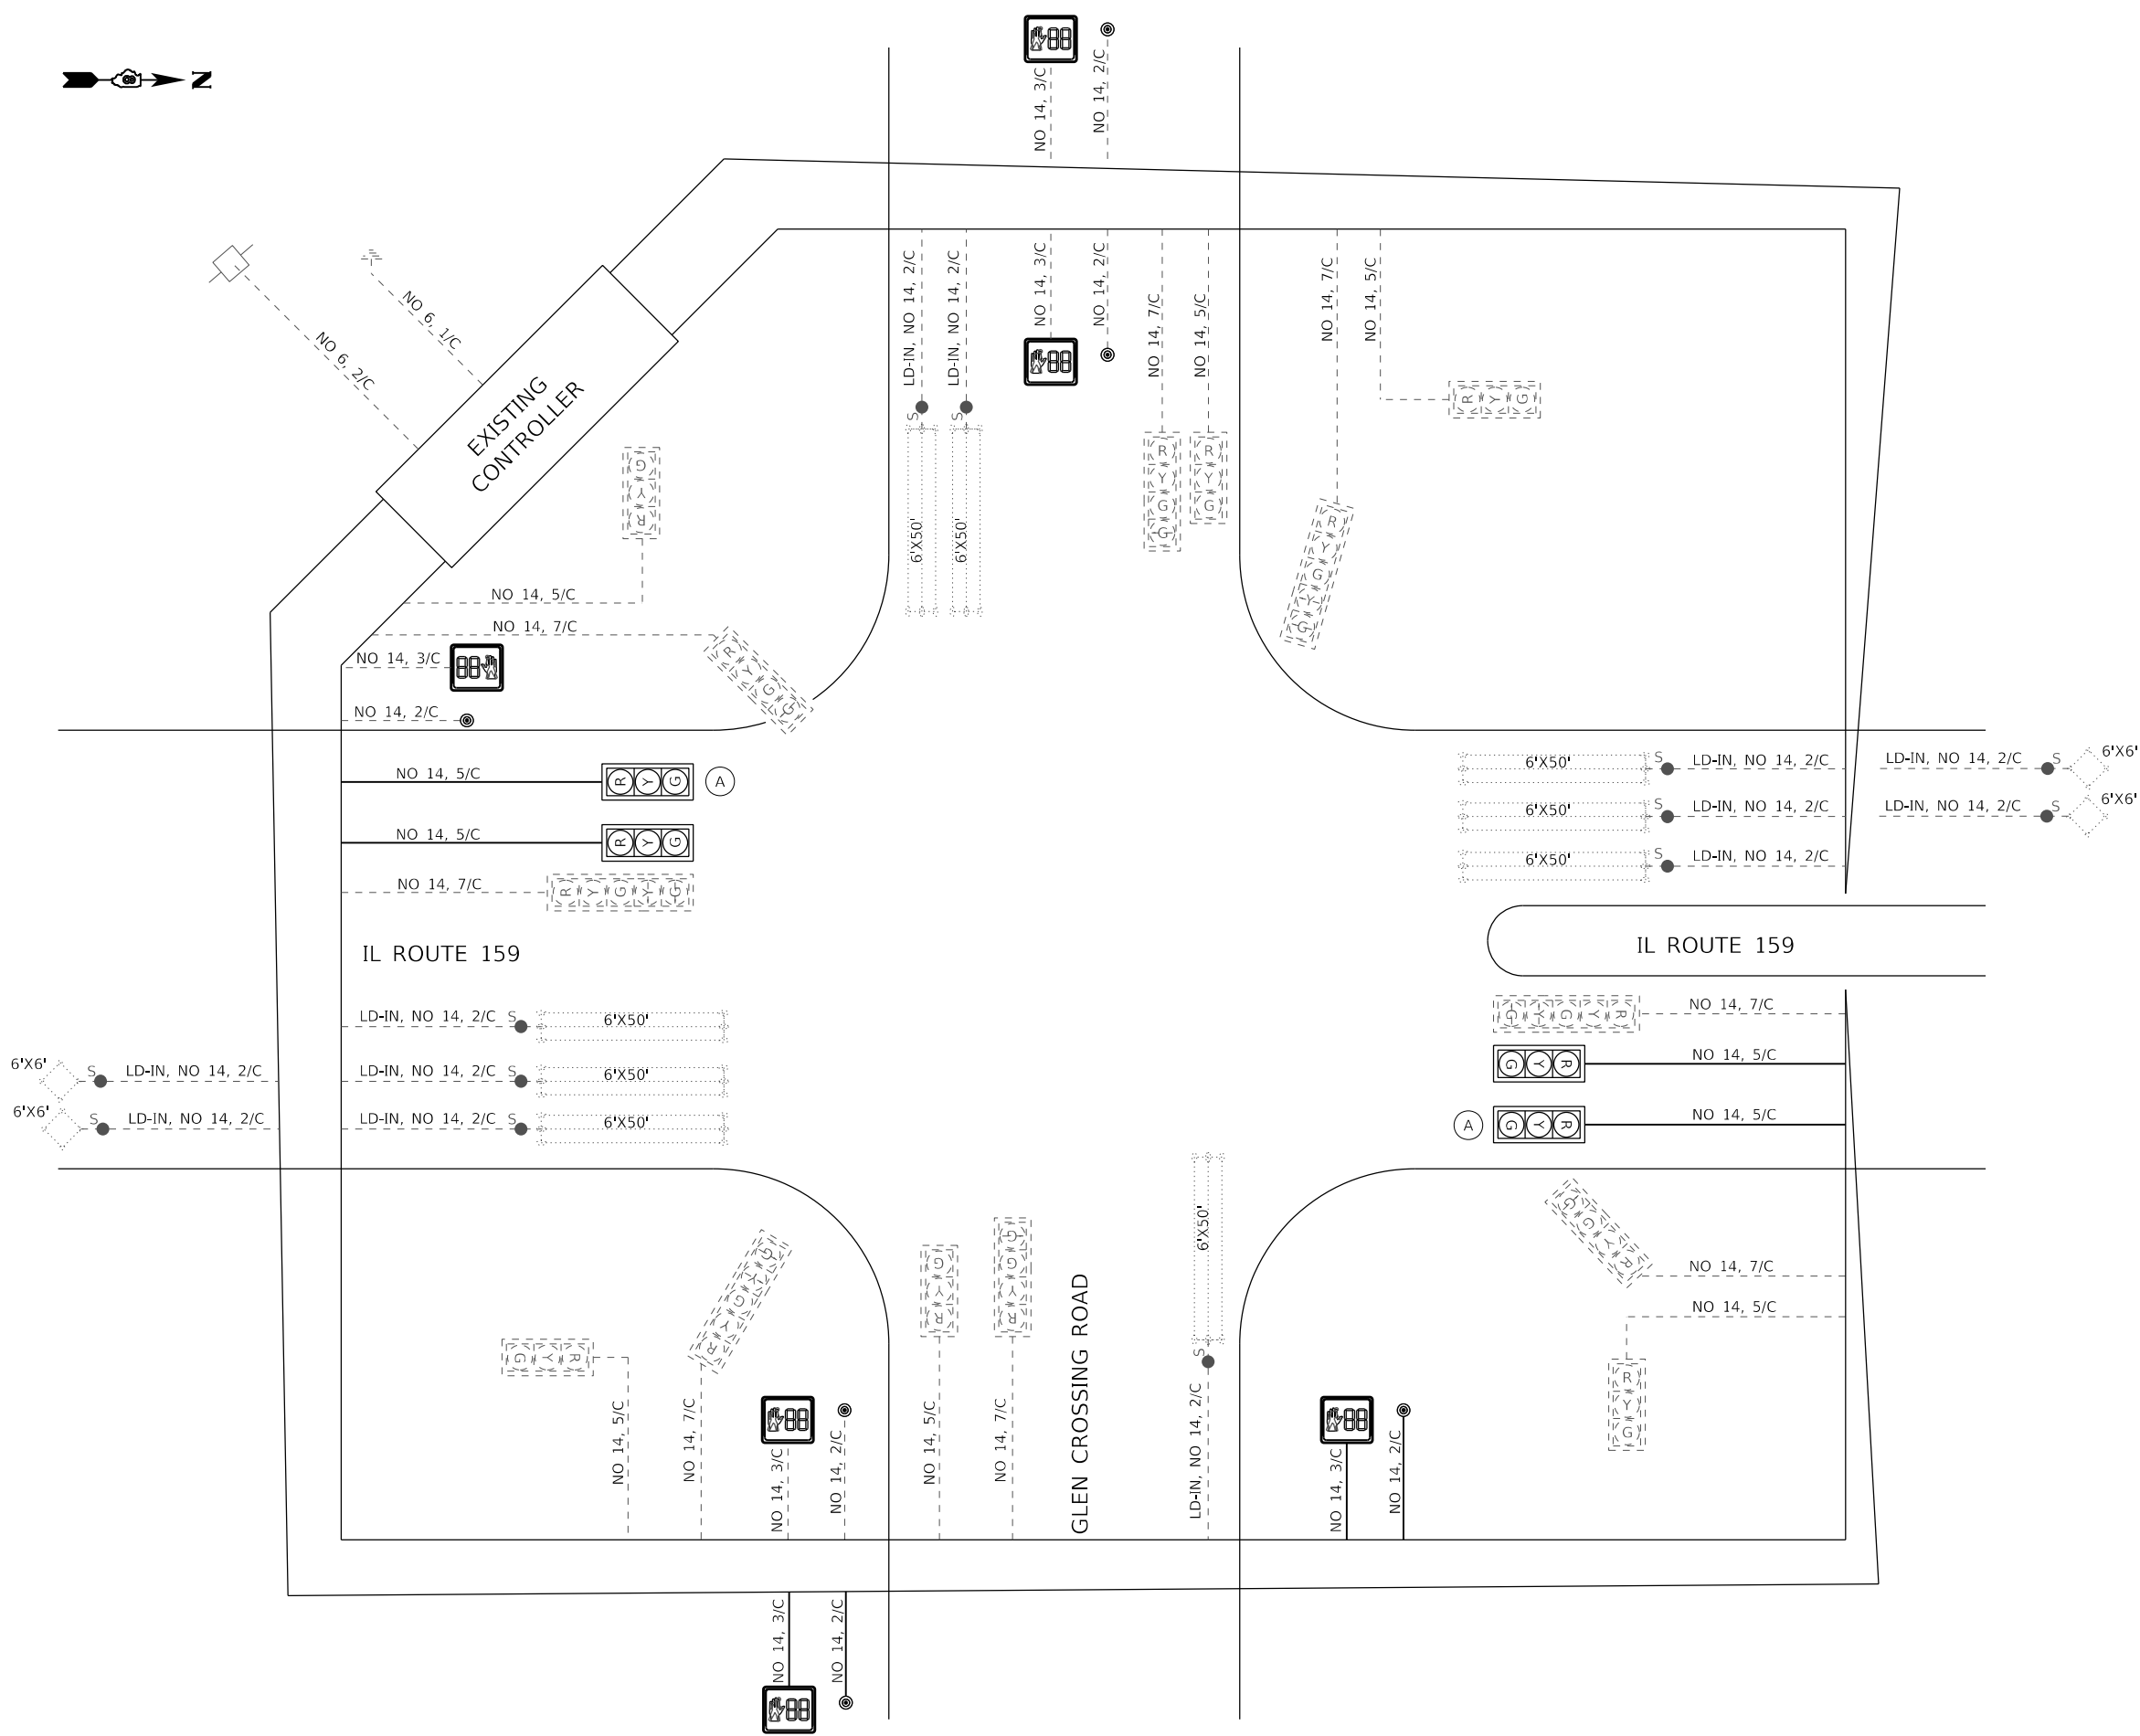

EXISTING TRAFFIC SIGNAL FACES

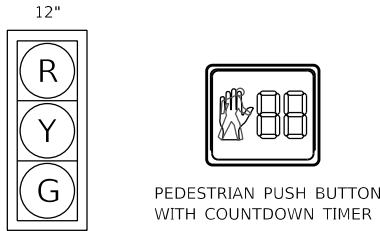


PROPOSED TRAFFIC SIGNAL FACES

(A) EXISTING SIGNAL HEAD AND BACK PLATE TO BE RELOCATED

CABLE DIAGRAM LEGEND

- PROPOSED PEDESTRIAN PUSH BUTTON
- PROPOSED ELECTRIC CABLE IN CONDUIT
- INDICATES NUMBER OF CONDUCTORS IN CABLE
- INDICATES AMERICAN WIRE (AWG) SIZE 6
- EXISTING ELECTRIC CABLE IN CONDUIT
- EXISTING PEDESTRIAN PUSH BUTTON
- EXISTING SERVICE INSTALLATION
- CABLE SPLICE

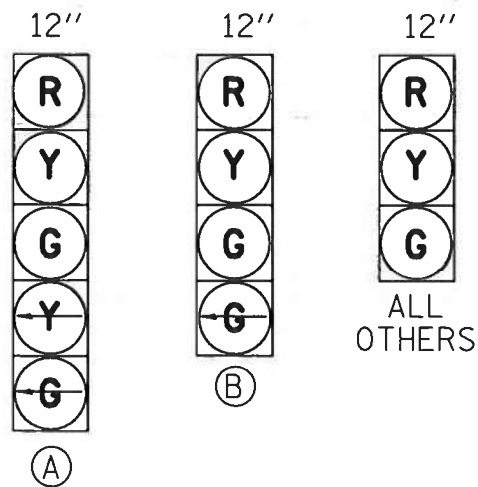

PROPOSED TRAFFIC SIGNAL FACES

EXNW BM-EXHH01, EX. 2" COND.-4'
REM & RE ELCBL FR CON-70'
REM & RE ELCBL FR CON-56'
ELCBL C SIGNAL 14 5C-20'
ELCBL C SIGNAL 14 7C-20'

EXHH01-EXDHH01, EX. 2 1/2" COND.-106'
7-REM & RE ELCBL FR CON-112' (EACH)
ELCBL C SIGNAL 14 5C-112'
ELCBL C SIGNAL 14 7C-112'

EXSW BM-DHH01, EX. 2" COND.-5'
REM & RE ELCBL FR CON-78'
REM & RE ELCBL FR CON-60'
ELCBL C SIGNAL 14 5C-21'
ELCBL C SIGNAL 14 7C-21'

EXDHH01-CNTRL, EX. 2-4" COND.-9'
20-REM & RE ELCBL FR CON-25' (EACH)
4-ELCBL C SIGNAL 14 5C-25' (EACH)
4-ELCBL C SIGNAL 14 7C-25' (EACH)

MOD EX CONTR CAB-1 EACH
MOD EX CONTR-1 EACH


EXHH02-EXDHH01, EX. 3" COND.-134'
9-REM & RE ELCBL FR CON-140' (EACH)
2-ELCBL C SIGNAL 14 5C-140' (EACH)
2-ELCBL C SIGNAL 14 7C-140' (EACH)

EXNE BM-EXHH03, EX. 2" COND.-13'
REM & RE ELCBL FR CON-83'
REM & RE ELCBL FR CON-65'
ELCBL C SIGNAL 14 5C-29'
ELCBL C SIGNAL 14 7C-29'

EXHH02-EXHH03, EX. 2 1/2" COND.-65'
3-REM & RE ELCBL FR CON-72' (EACH)
ELCBL C SIGNAL 14 5C-72'
ELCBL C SIGNAL 14 7C-72'

EXSE BM-EXHH02, EX. 2" COND.-5'
REM & RE ELCBL FR CON-64'
REM & RE ELCBL FR CON-32'
ELCBL C SIGNAL 14 5C-20'
ELCBL C SIGNAL 14 7C-20'

SCHEDULE OF QUANTITIES			
CODE NO.	ITEM	UNIT	QTY.
70102637	TRAFFIC CONTROL AND PROTECTION, STANDARD 701701	EACH	1
70102642	TRAFFIC CONTROL AND PROTECTION, STANDARD 701801	EACH	1
87301245	ELECTRIC CABLE IN CONDUIT, SIGNAL NO. 14 5C	FOOT	654
87301255	ELECTRIC CABLE IN CONDUIT, SIGNAL NO. 14 7C	FOOT	654
88040250	SIGNAL HEAD, POLYCARBONATE, LED, 2-FACE, 1-3-SECTION, 1-4-SECTION, BRACKET MOUNTED	EACH	2
88040260	SIGNAL HEAD, POLYCARBONATE, LED, 2-FACE, 1-3-SECTION, 1-5-SECTION, BRACKET MOUNTED	EACH	2
89502200	MODIFY EXISTING CONTROLLER	EACH	1
89502210	MODIFY EXISTING CONTROLLER CABINET	EACH	1
89502350	REMOVE AND REINSTALL ELECTRIC CABLE FROM CONDUIT	FOOT	3268

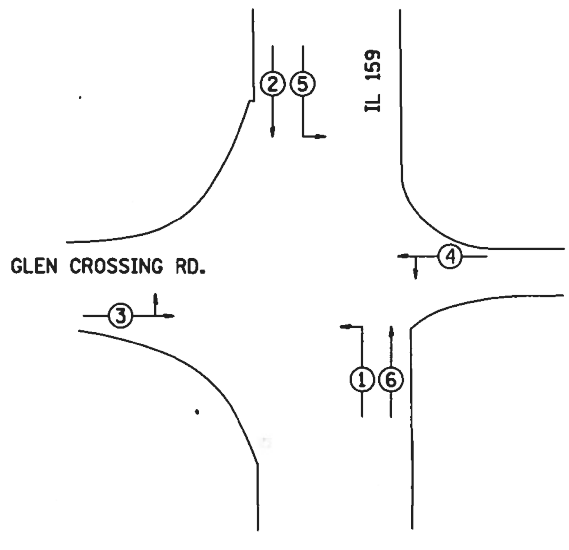

MODEL: Default
FILE NAME: 1030066_10DOT-DH01-PTB194_05190606_010_WC1 IL 159 Design 007 6M87-2nd-AS-Built.dgn




USER NAME	= nseelhoefer	DESIGNED	-	REVISED	-
PLOT SCALE	= 0.1667" / in.	DRAWN	-	REVISED	-
PLOT DATE	= 6/30/2022	CHECKED	-	REVISED	-
		DATE	-	REVISED	-

STATE OF ILLINOIS
DEPARTMENT OF TRANSPORTATION

AS BUILT
IL ROUTE 159 & GLEN CROSSING ROAD

SCALE: SHEET OF SHEETS STA. TO STA.

FAU RTE	SECTION	COUNTY	TOTAL SHEETS	SHEET NO.
8887	(122,122-1,30)RS-4	MADISON	328	267A
CONTRACT NO. 76M87				
ILLINOIS FED. AID PROJECT				

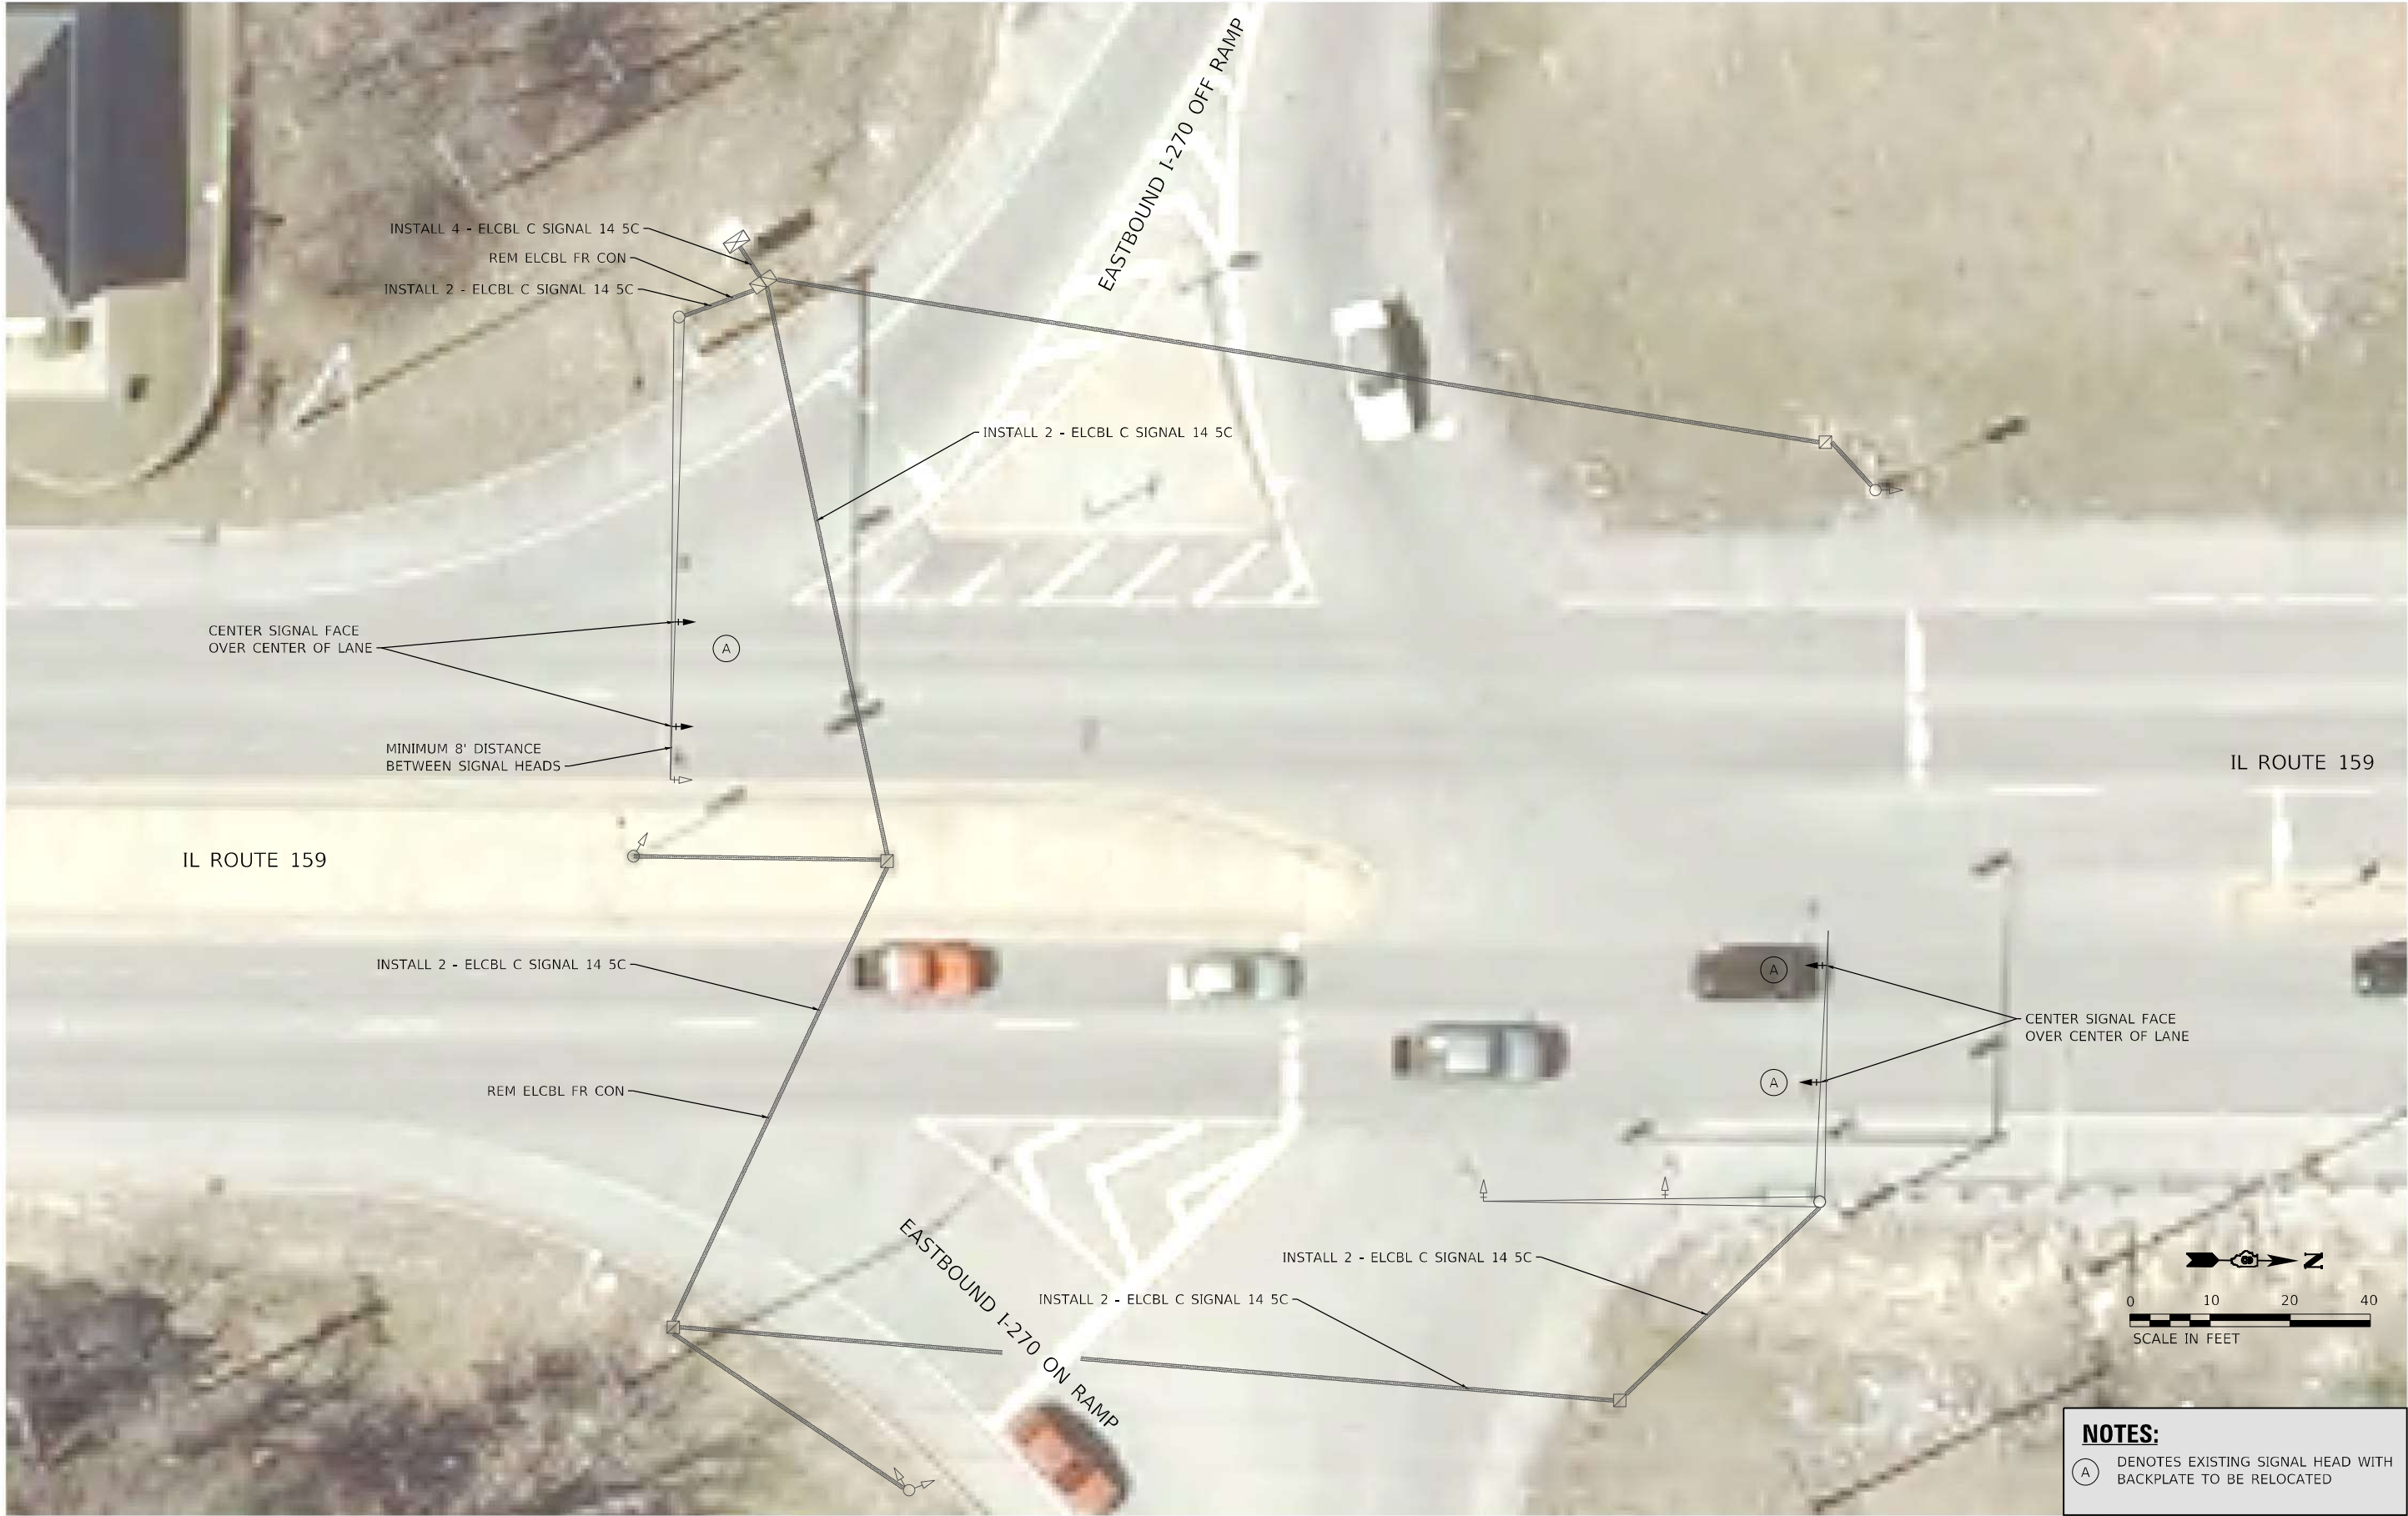

NOTES:
(A) DENOTES EXISTING SIGNAL HEAD WITH BACKPLATE TO BE RELOCATED

MODEL: Sheet 12 - I-270 S Junction
FILE NAME: 108248_170_139_022020_010_W01_IL159_Traffic_Signal_Upgrade\Card_Sheets\0876M87-11.dgn

HMG
ENGINEERS
IL PROF DESIGN FIRM 184,000899

USER NAME = nseelhoefer	DESIGNED -	REVISED -
	DRAWN -	REVISED -
PLOT SCALE = 20,000' / in.	CHECKED -	REVISED -
PLOT DATE = 6/30/2022	DATE -	REVISED -

STATE OF ILLINOIS
DEPARTMENT OF TRANSPORTATION

TRAFFIC SIGNAL PLANS
IL ROUTE 159 & I-270 S JUNCTION

SCALE: 1" = 10' SHEET TS 12 OF 31 SHEETS STA. TO STA.

F.A.P. RTE.	SECTION	COUNTY	TOTAL SHEETS	SHEET NO.
600	(122,122-1,30)RS-4	MADISON	328	268
CONTRACT NO. 76M87				
ILLINOIS FED. AID PROJECT				

MODEL: Sheet 27 - I-270 S Junction
FILE NAME: 108249_P09_199_02282019_010_W01_IL159_Traffic_Signal_Upgrade\Card_Sheets\0876M87-Cable_Diagrams.dgn



USER NAME	= nseelhoefer
PLOT SCALE	= 10,0000 ' / in.
PLOT DATE	= 6/30/2022

DESIGNED	-
DRAWN	-
CHECKED	-
DATE	-


REVISED	-
REVISED	-
REVISED	-
REVISED	-

STATE OF ILLINOIS
DEPARTMENT OF TRANSPORTATION


CABLE DIAGRAM
IL ROUTE 159 & I-270 S JUNCTION

SCALE: NTS SHEET TS 27 OF 31 SHEETS STA. TO STA.

F.A.P. RTE.	SECTION	COUNTY	TOTAL SHEETS	SHEET NO.
600	(122,122-1,30)RS-4	MADISON	328	269
CONTRACT NO. 76M87				
ILLINOIS FED. AID PROJECT				

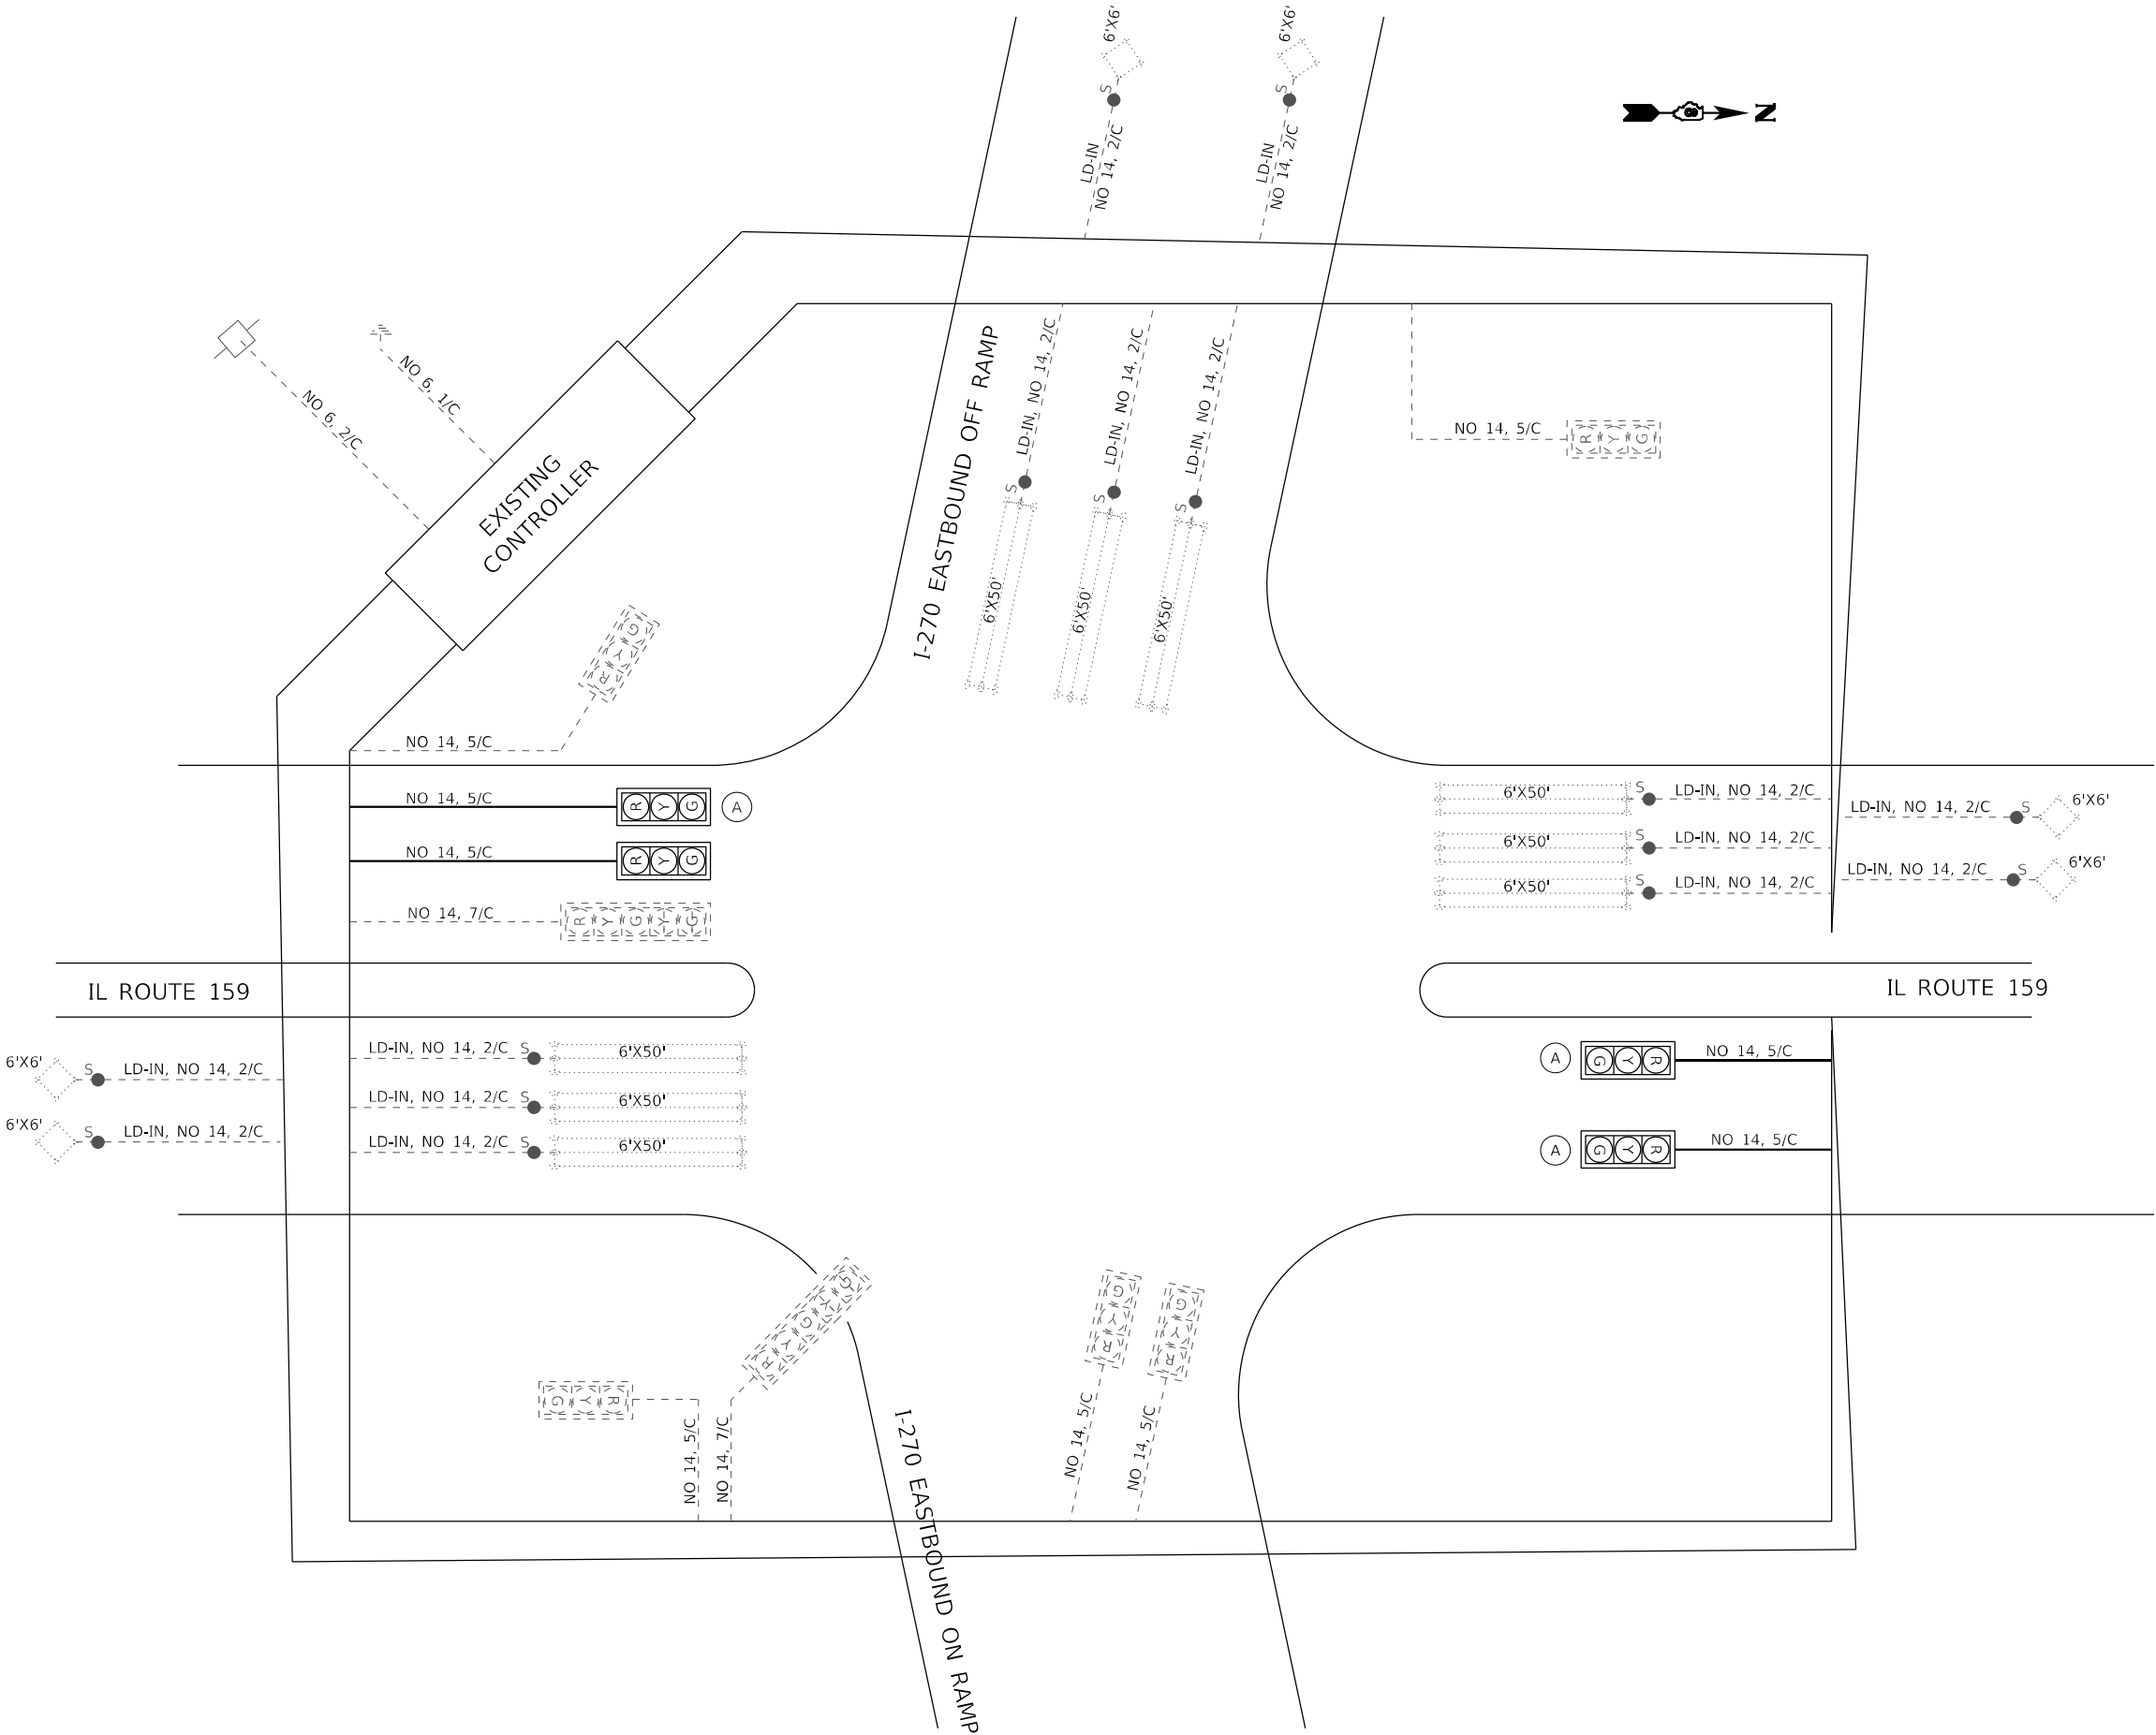


EXISTING TRAFFIC SIGNAL FACES

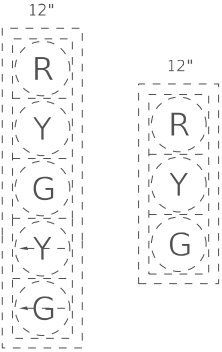

PROPOSED TRAFFIC SIGNAL FACES

 (A) EXISTING SIGNAL HEAD AND BACK PLATE TO BE RELOCATED



CABLE DIAGRAM LEGEND

 
- PROPOSED ELECTRIC CABLE IN CONDUIT
- 2/C INDICATES NUMBER OF CONDUCTORS IN CABLE
- NO. 6 INDICATES AMERICAN WIRE (AWG) SIZE 6
- EXISTING ELECTRIC CABLE IN CONDUIT
- EXISTING PEDESTRIAN PUSH BUTTON
- EXISTING SERVICE INSTALLATION
- CABLE SPLICE

12"




(A)

12"




ALL
OTHERS

PROPOSED TRAFFIC SIGNAL FACES

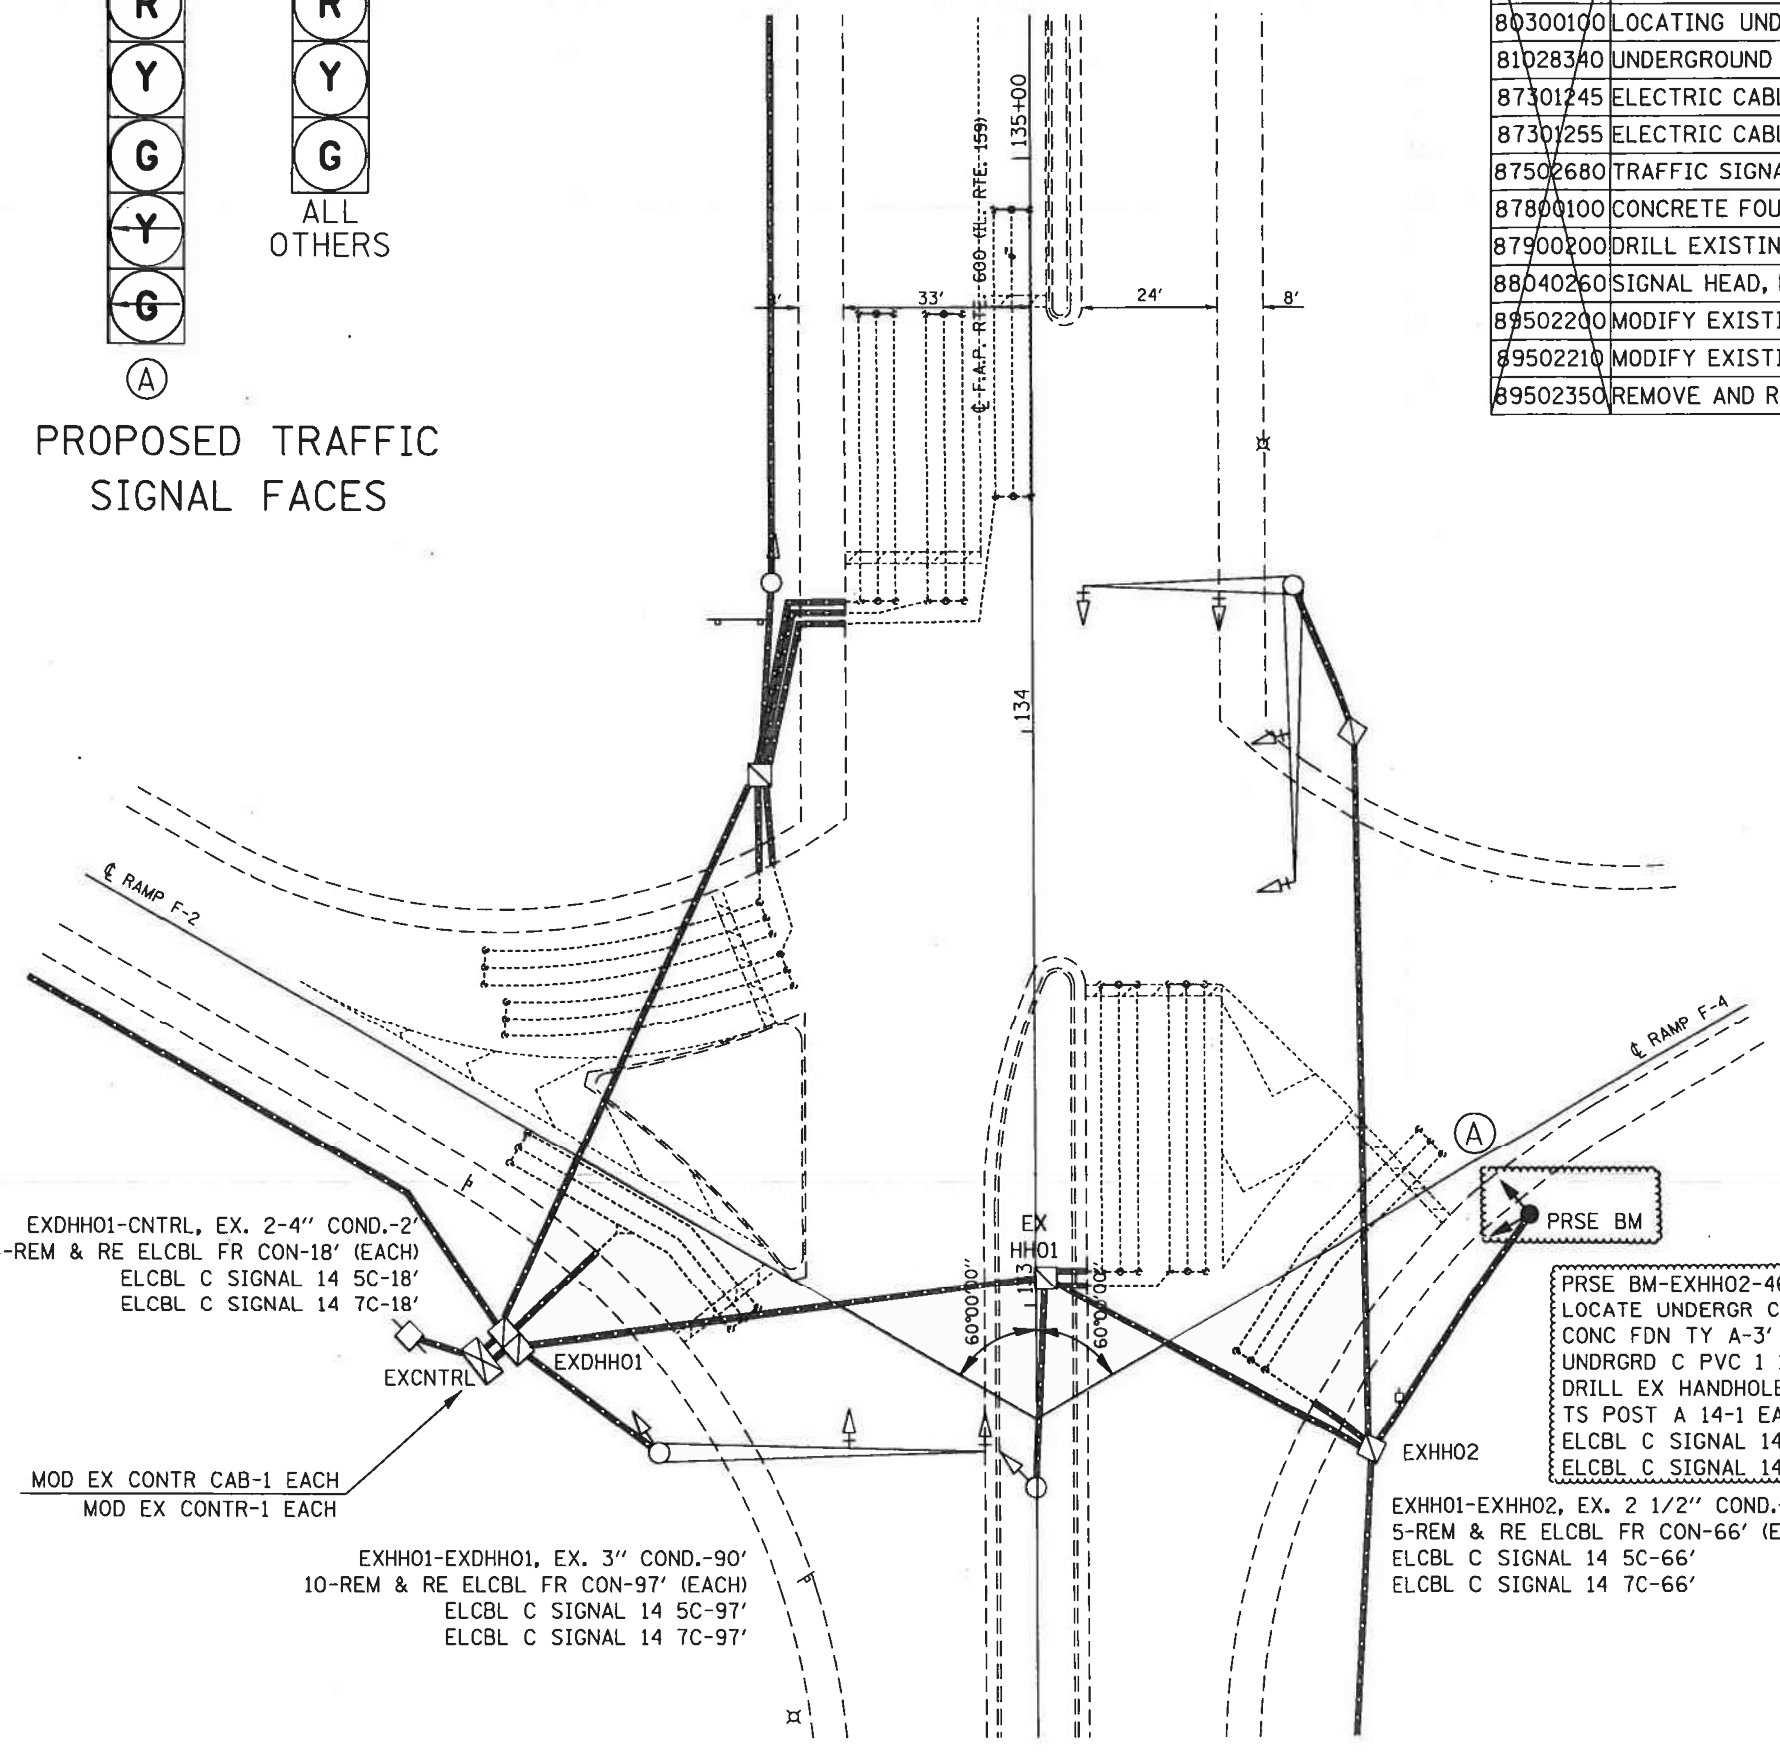

SCHEDULE OF QUANTITIES			
CODE NO.	ITEM	UNIT	QTY.
70102637	TRAFFIC CONTROL AND PROTECTION, STANDARD 701701	EACH	1
80300100	LOCATING UNDERGROUND CABLE	FOOT	46
81028340	UNDERGROUND CONDUIT, PVC, 1 1/2" DIA.	FOOT	46
87301245	ELECTRIC CABLE IN CONDUIT, SIGNAL NO. 14 5C	FOOT	243
87301255	ELECTRIC CABLE IN CONDUIT, SIGNAL NO. 14 7C	FOOT	243
87502680	TRAFFIC SIGNAL POST, ALUMINUM 14 FT.	EACH	1
87800100	CONCRETE FOUNDATION, TYPE A	FOOT	3
87900200	DRILL EXISTING HANDHOLE	EACH	1
88040260	SIGNAL HEAD, POLYCARBONATE, LED, 2-FACE, 1-3-SECTION, 1-5-SECTION, BRACKET MOUNTED	EACH	1
89502200	MODIFY EXISTING CONTROLLER	EACH	1
89502210	MODIFY EXISTING CONTROLLER CABINET	EACH	1
89502350	REMOVE AND REINSTALL ELECTRIC CABLE FROM CONDUIT	FOOT	1732

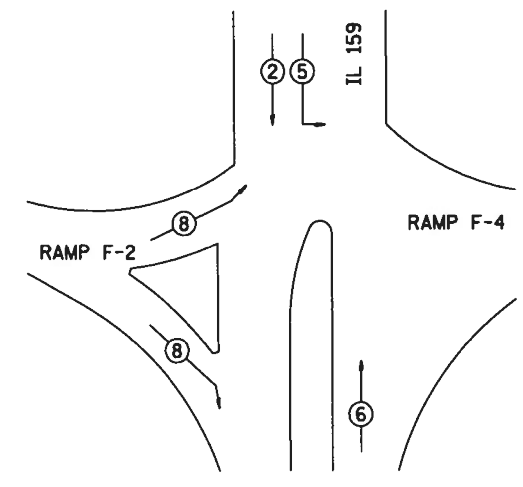

PHASE DESIGNATION
DIAGRAM

EXISTING FULL-ACTUATED CONTROLLER

EXISTING SEQUENCE OF OPERATION								
PHASE	1	2	3	4	5	6	7	8
MOVEMENT	NOT USED	↓	NOT USED	NOT USED	↙	↑	NOT USED	↘
CONCURRENT MOVEMENT PERMITTED		5 OR 6			2	2		NONE


PRSE BM-EXHH02-46'
LOCATE UNDERGR CABLE-46'
CONC FDN TY A-3'
UNDRGRD C PVC 1 1/2-46'
DRILL EX HANDHOLE-1 EACH
TS POST A 14-1 EACH
ELCBL C SIGNAL 14 5C-62'
ELCBL C SIGNAL 14 7C-62'

EXHH01-EXHH02, EX. 2 1/2" COND.-60'
5-REM & RE ELCBL FR CON-66' (EACH)
ELCBL C SIGNAL 14 5C-66'
ELCBL C SIGNAL 14 7C-66'

EXDH01-CNTRL, EX. 2-4" COND.-2'
24-REM & RE ELCBL FR CON-18' (EACH)
ELCBL C SIGNAL 14 5C-18'
ELCBL C SIGNAL 14 7C-18'

MOD EX CONTR CAB-1 EACH
MOD EX CONTR-1 EACH

 EXHH01-EXDH01, EX. 3" COND.-90'
10-REM & RE ELCBL FR CON-97' (EACH)
ELCBL C SIGNAL 14 5C-97'
ELCBL C SIGNAL 14 7C-97'



MODEL: Default
FILE NAME: 1030066_10DOT.DWG
PLOT DATE: 6/30/2022
PLOT SCALE: 0.1667" / 1'




USER NAME	= nseelhoefer	DESIGNED	-	REVISED	-
DRAWN	-	REVISION	-	REVISION	-
CHECKED	-	REVISION	-	REVISION	-
DATE	-	REVISION	-	REVISION	-

STATE OF ILLINOIS
DEPARTMENT OF TRANSPORTATION

AS BUILTS
IL ROUTE 159 & I-270 S JUNCTION

SCALE: SHEET OF SHEETS STA. TO STA.

FAU RTE	SECTION	COUNTY	TOTAL SHEETS	SHEET NO.
8887	(122,122-1,30)RS-4	MADISON	328	269A
CONTRACT NO. 76M87				
ILLINOIS FED. AID PROJECT				

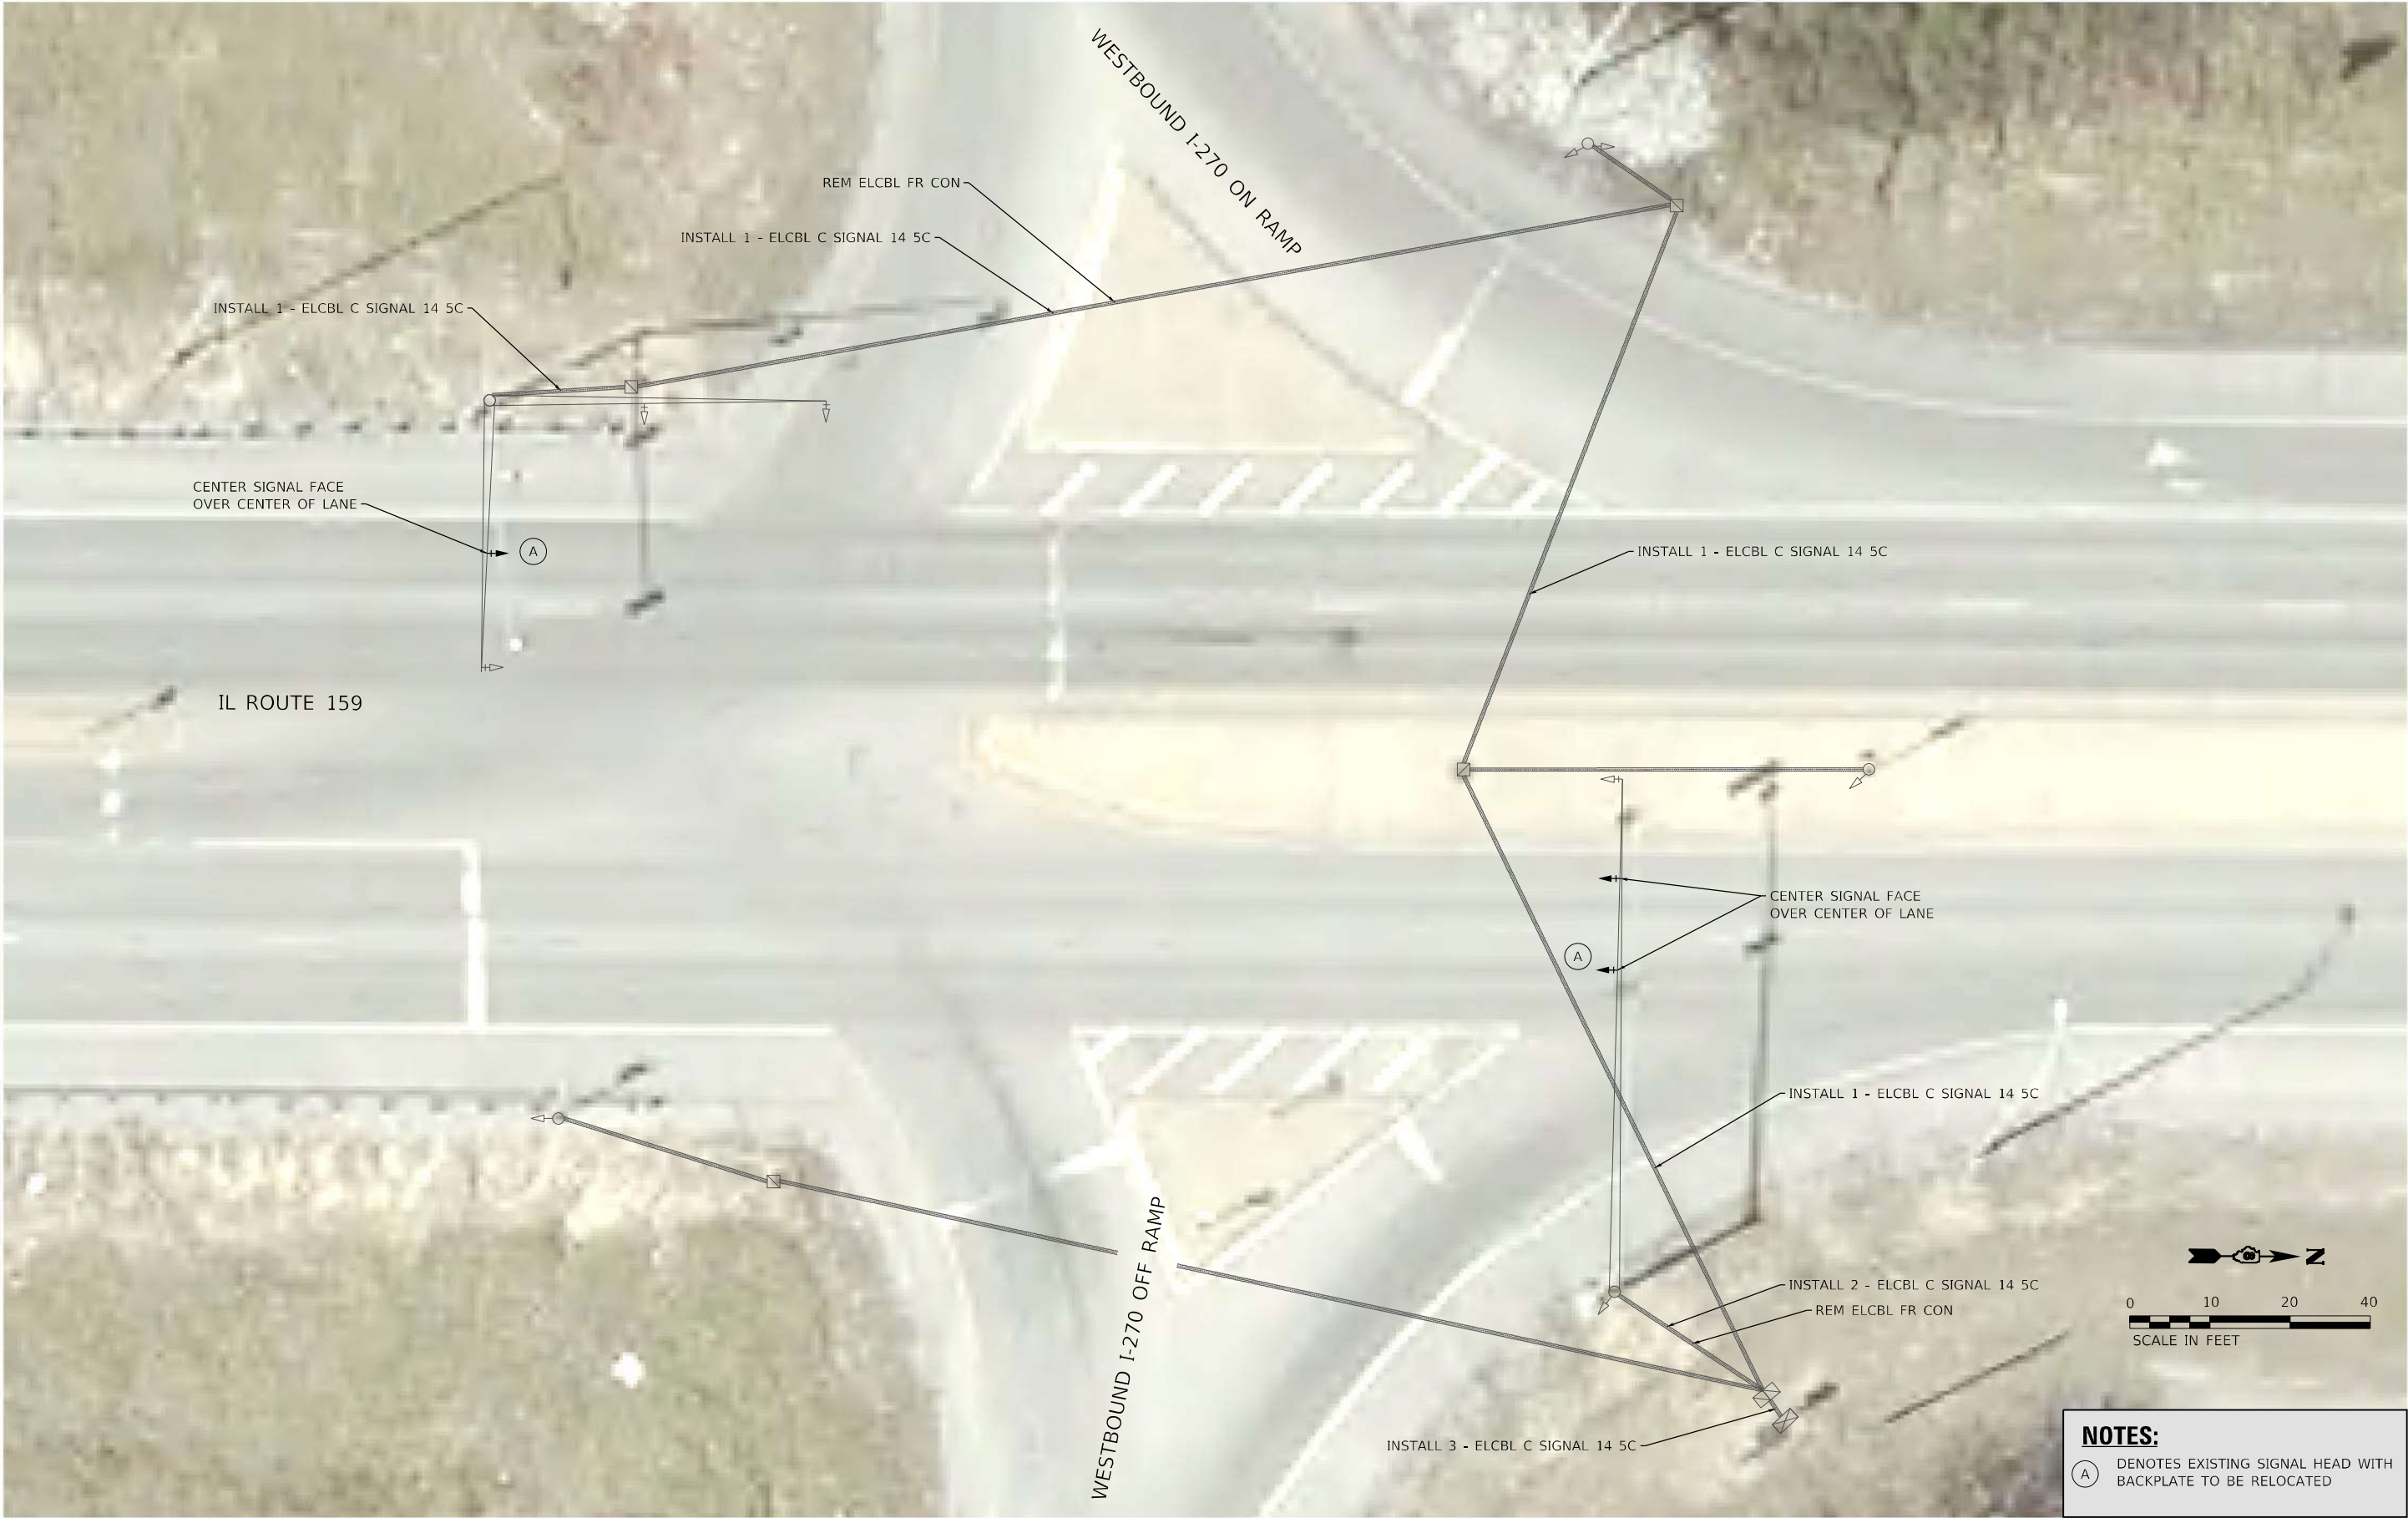

MODEL: Sheet 13 - I-270 N Junction
FILE NAME: 108249_1703_199_02202019_010_WO1_IL159_Traffic_Signal_Upgrade\Card_Sheets\0876M87-11.dgn

USER NAME	= nseelhoefer	DESIGNED	-	REVISED	-
		DRAWN	-	REVISED	-
PLOT SCALE	= 20,0000 ' / in.	CHECKED	-	REVISED	-
PLOT DATE	= 6/30/2022	DATE	-	REVISED	-

TRAFFIC SIGNAL PLANS			
IL ROUTE 159 & I-270 N JUNCTION			
SCALE: 1" = 10'	SHEET TS 13 OF 31 SHEETS	STA.	TO STA.

F.A.P. RTE.	SECTION	COUNTY	TOTAL SHEETS	SHEET NO.
600	(122,122-1,30)RS-4	MADISON	328	270
CONTRACT NO. 76M87				
ILLINOIS FED. AID PROJECT				

MODEL: Sheet 28 - I-270, N. Junction
FILE NAME: I:\82949_7709_199_02182021\9_010_WO1_IL159_Traffic_Signal_Upgrade\Cable_Sheets\0876M87-Cable_Diagrams.dgn



USER NAME	= nseelhoefer
PLOT SCALE	= 10,0000 ' / in.
PLOT DATE	= 6/30/2022

DESIGNED	-
DRAWN	-
CHECKED	-
DATE	-


REVISED	-
REVISED	-
REVISED	-
REVISED	-

STATE OF ILLINOIS
DEPARTMENT OF TRANSPORTATION


CABLE DIAGRAM
IL ROUTE 159 & I-270 NORTH JUNCTION

SCALE: NTS SHEET TS 28 OF 31 SHEETS STA. TO STA.

F.A.P. RTE.	SECTION	COUNTY	TOTAL SHEETS	SHEET NO.
600	(122,122-1,30)RS-4	MADISON	328	271
CONTRACT NO. 76M87				
ILLINOIS FED. AID PROJECT				

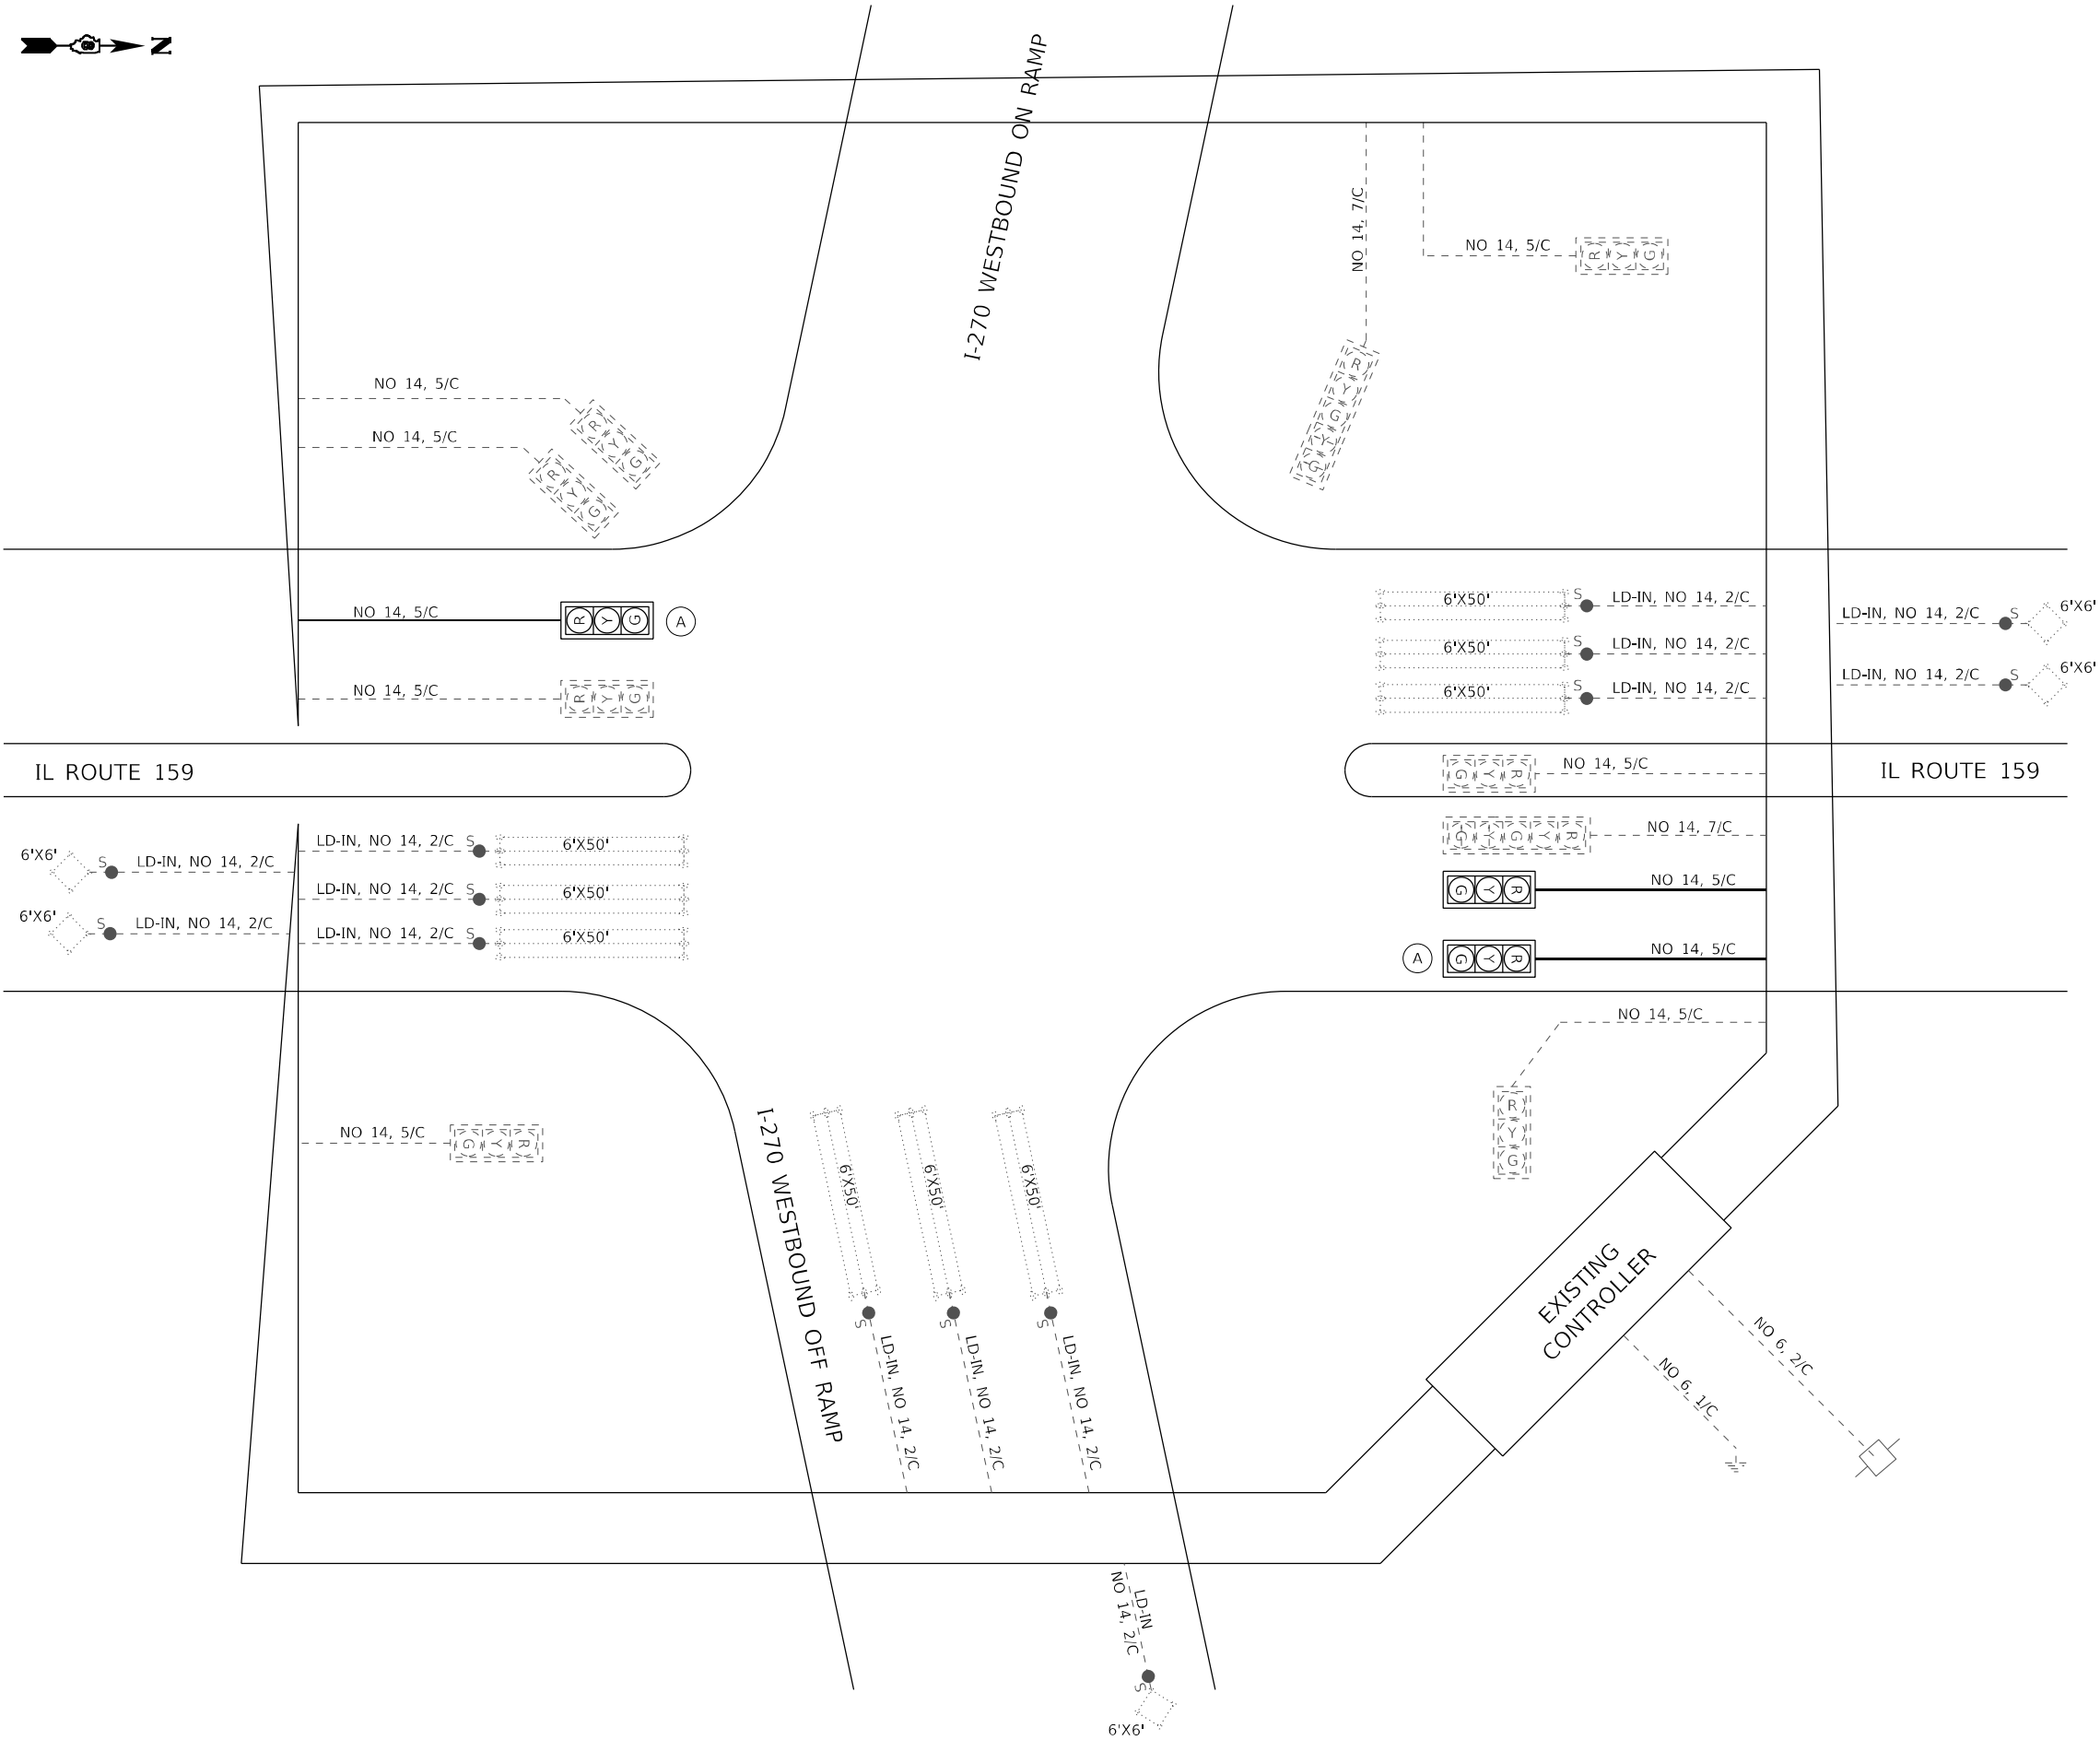

EXISTING TRAFFIC SIGNAL FACES

 


PROPOSED TRAFFIC SIGNAL FACES


(A) EXISTING SIGNAL HEAD AND BACK PLATE TO BE RELOCATED

CABLE DIAGRAM LEGEND


- PROPOSED ELECTRIC CABLE IN CONDUIT
- 2/C INDICATES NUMBER OF CONDUCTORS IN CABLE
- NO. 6 INDICATES AMERICAN WIRE (AWG) SIZE 6
- EXISTING ELECTRIC CABLE IN CONDUIT
- EXISTING PEDESTRIAN PUSH BUTTON
- EXISTING SERVICE INSTALLATION
- CABLE SPLICE

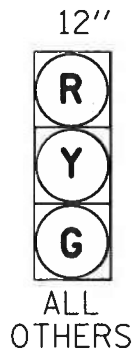


PROPOSED TRAFFIC
SIGNAL FACES

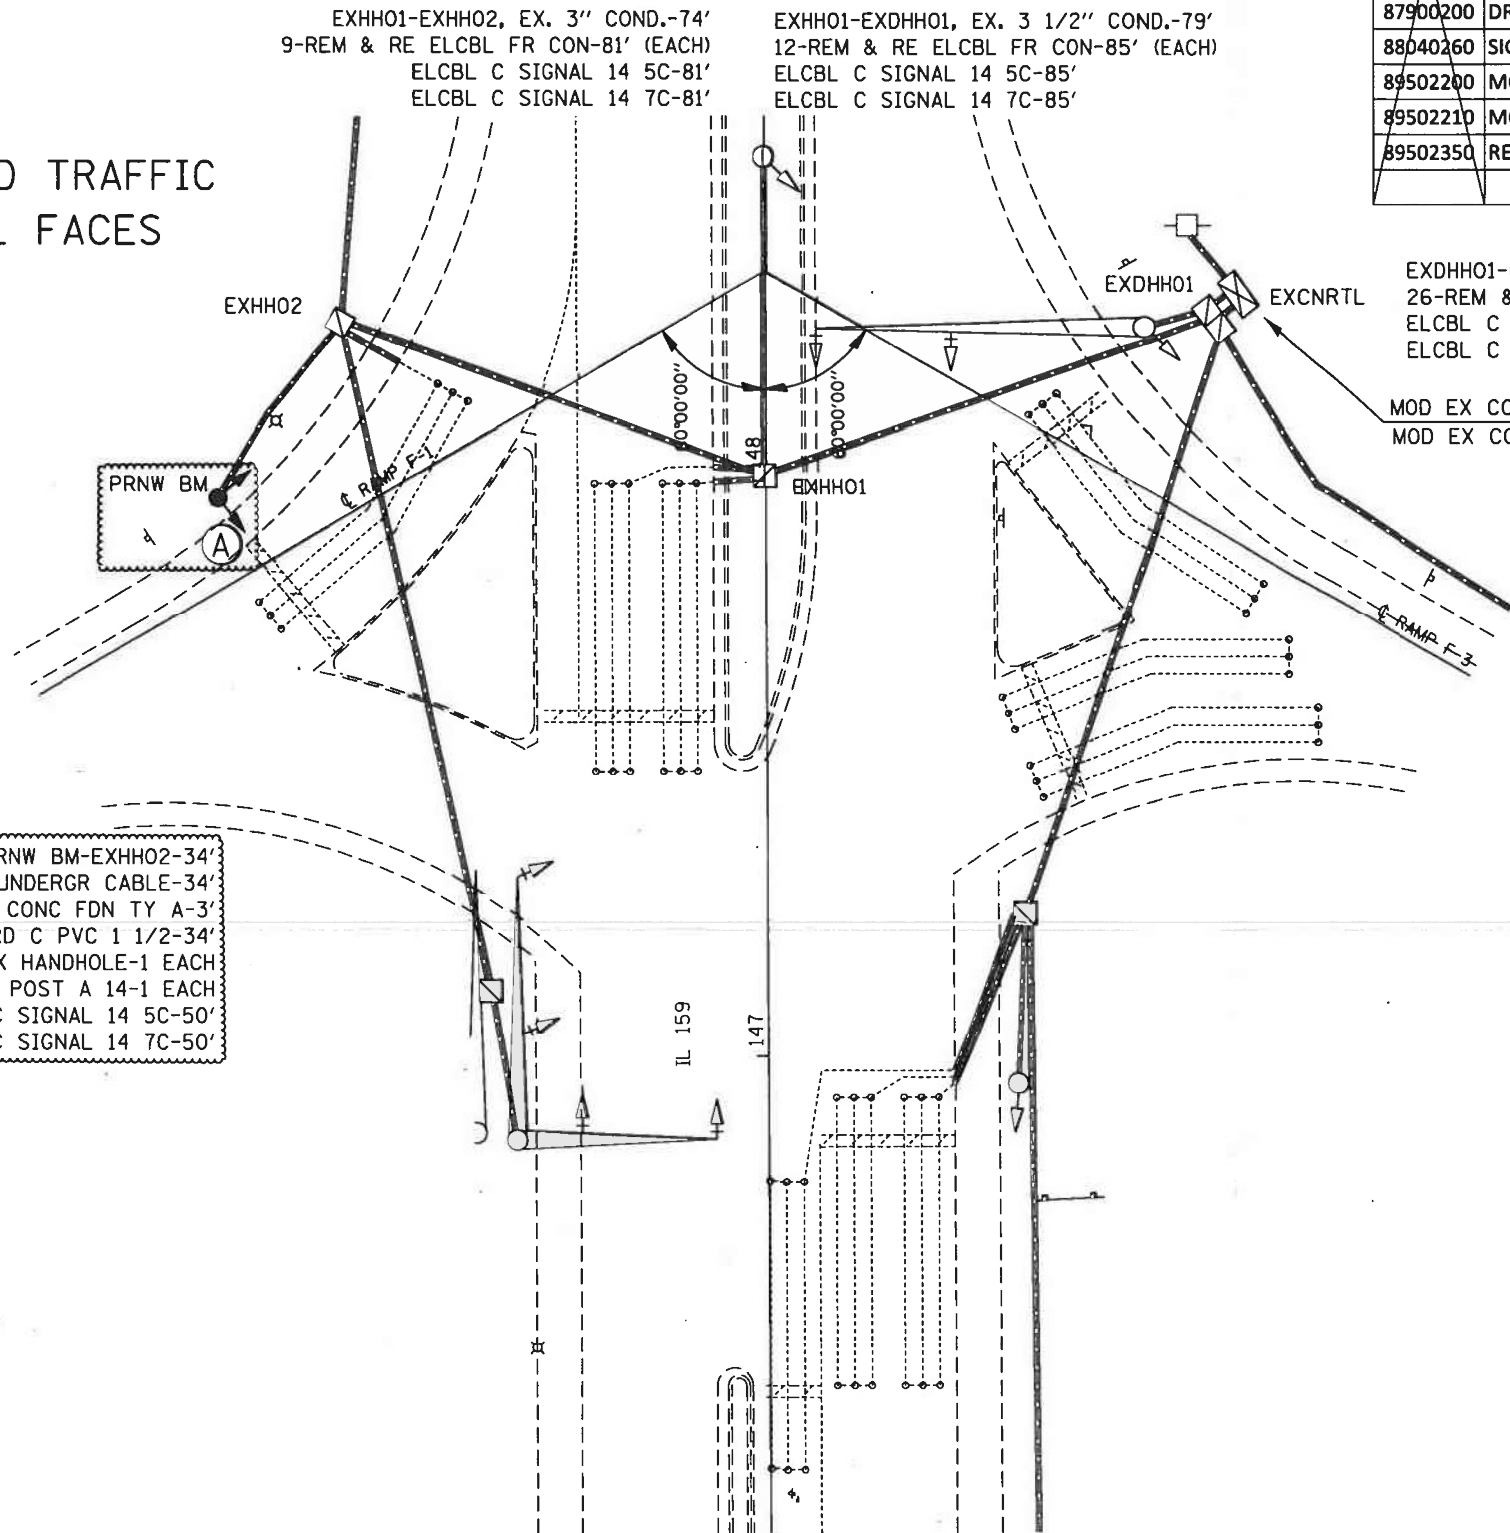

SCHEDULE OF QUANTITIES			
CODE NO.	ITEM	UNIT	QTY.
70102637	TRAFFIC CONTROL AND PROTECTION, STANDARD 701701	EACH	1
80300100	LOCATING UNDERGROUND CABLE	FOOT	34
81028340	UNDERGROUND CONDUIT, PVC, 1 1/2" DIA.	FOOT	34
87801745	ELECTRIC CABLE IN CONDUIT, SIGNAL NO. 14 5C	FOOT	234
87301255	ELECTRIC CABLE IN CONDUIT, SIGNAL NO. 14 7C	FOOT	234
87502680	TRAFFIC SIGNAL POST, ALUMINUM 14 FT.	EACH	1
87800100	CONCRETE FOUNDATION, TYPE A	FOOT	3
87900200	DRILL EXISTING HANDHOLE	EACH	1
88040260	SIGNAL HEAD, POLYCARBONATE, LED, 2-FACE, 1-3-SECTION, 1-5-SECTION, BRACKET MOUNTED	EACH	1
89502200	MODIFY EXISTING CONTROLLER	EACH	1
89502210	MODIFY EXISTING CONTROLLER CABINET	EACH	1
89502350	REMOVE AND REINSTALL ELECTRIC CABLE FROM CONDUIT	FOOT	2217

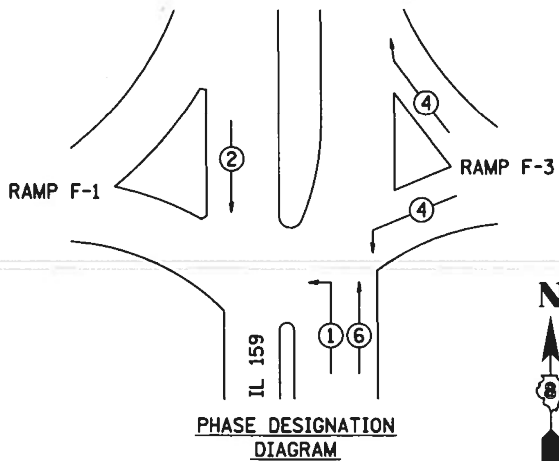

EXISTING FULL-ACTUATED CONTROLLER								
EXISTING SEQUENCE OF OPERATION								
PHASE	1	2	3	4	5	6	7	8
MOVEMENT	↖	↓	NOT USED	↗	NOT USED	↑	NOT USED	NOT USED
CONCURRENT MOVEMENT PERMITTED	6	6		NONE		1 OR 2		

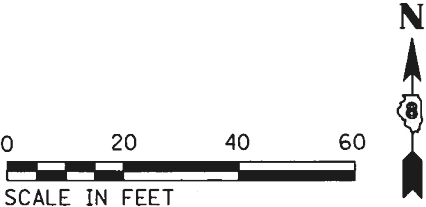

MODEL: Default
FILE NAME: 1030066_1DOT.DWG
PLOT DATE: 6/30/2022
PLOT SCALE: 0.1667" = 1'-0"

HMG
ENGINEERS
IL PROF DESIGN FIRM 184,000899


USER NAME	= nseelhoefer	DESIGNED	-	REVISED	-
DRAWN	-	REVISION	-	REVISION	-
PLOT SCALE	= 0.1667" / 1'-0"	CHECKED	-	REVISION	-
PLOT DATE	= 6/30/2022	DATE	-	REVISION	-

STATE OF ILLINOIS
DEPARTMENT OF TRANSPORTATION

AS BUILTS
IL ROUTE 159 & I-270 N JUNCTION

SCALE: SHEET OF SHEETS STA. TO STA.

FAU RTE	SECTION	COUNTY	TOTAL SHEETS	SHEET NO.
8887	(122,122-1,30)RS-4	MADISON	328	271A
CONTRACT NO. 76M87				
ILLINOIS FED. AID PROJECT				

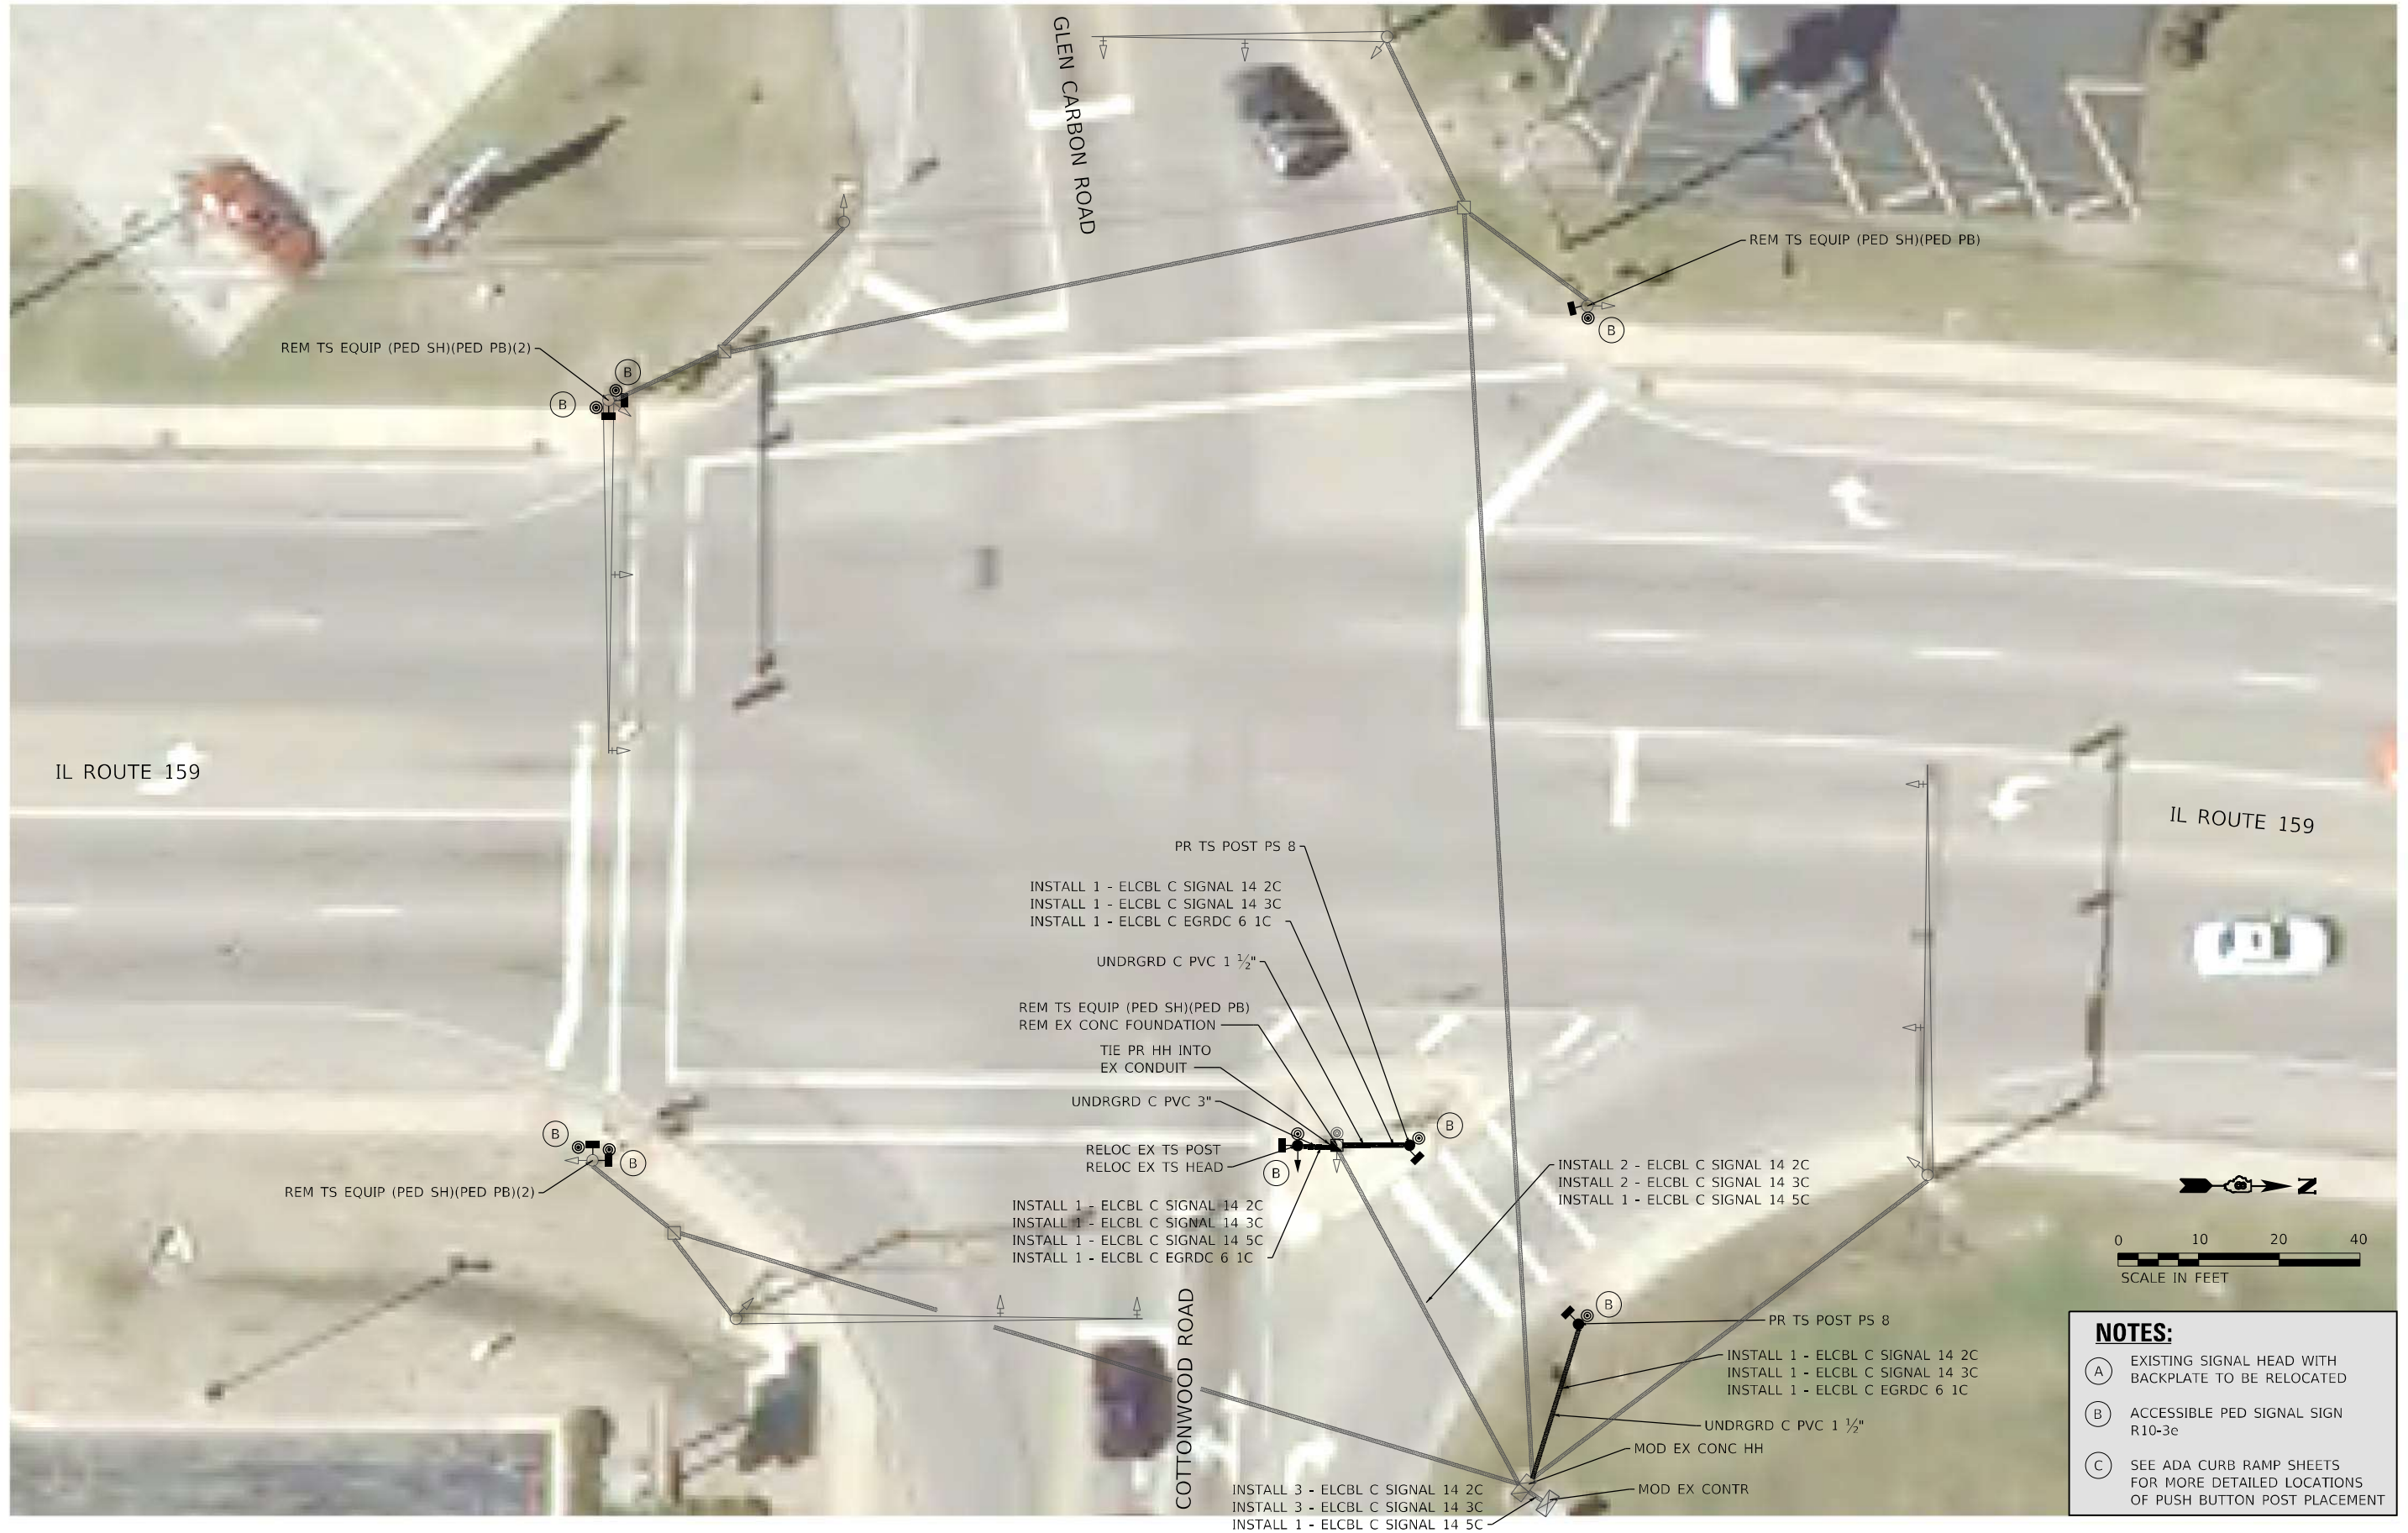

- NOTES:**
- (A) EXISTING SIGNAL HEAD WITH BACKPLATE TO BE RELOCATED
 - (B) ACCESSIBLE PED SIGNAL SIGN R10-3e
 - (C) SEE ADA CURB RAMP SHEETS FOR MORE DETAILED LOCATIONS OF PUSH BUTTON POST PLACEMENT

MODEL: Sheet 14 - Cottonwood
FILE NAME: 108249_001_159_0218249_010_W01_IL159_Traffic_Signal_Upgrade/Cadd_Sheets/0876M87-14.dgn

HMG
ENGINEERS
IL PROF DESIGN FIRM 184,000899

USER NAME	= nseelhoefer	DESIGNED	-	REVISED	-
DRAWN	-	REVIS	-	REVIS	-
PLOT SCALE	= 20,0000 ' / in.	CHECKED	-	REVISED	-
PLOT DATE	= 6/30/2022	DATE	-	REVISED	-


STATE OF ILLINOIS
DEPARTMENT OF TRANSPORTATION

TRAFFIC SIGNAL PLANS
IL RTE 159 & GLEN CARBON ROAD /COTTONWOOD ROAD


SCALE: 1" = 10' SHEET TS 14 OF 31 SHEETS STA. TO STA.

F.A.P. RTE.	SECTION	COUNTY	TOTAL SHEETS	SHEET NO.
600	(122,122-1,30)RS-4	MADISON	328	272
CONTRACT NO. 76M87				
ILLINOIS FED. AID PROJECT				

MODEL: Sheet 29 - Cottonwood
FILE NAME: 108294_00_139_02182949_010_W01_IL159_Traffic_Signal_Upgrade\Card_Sheets\0876M87-Cable_Diagram.dgn

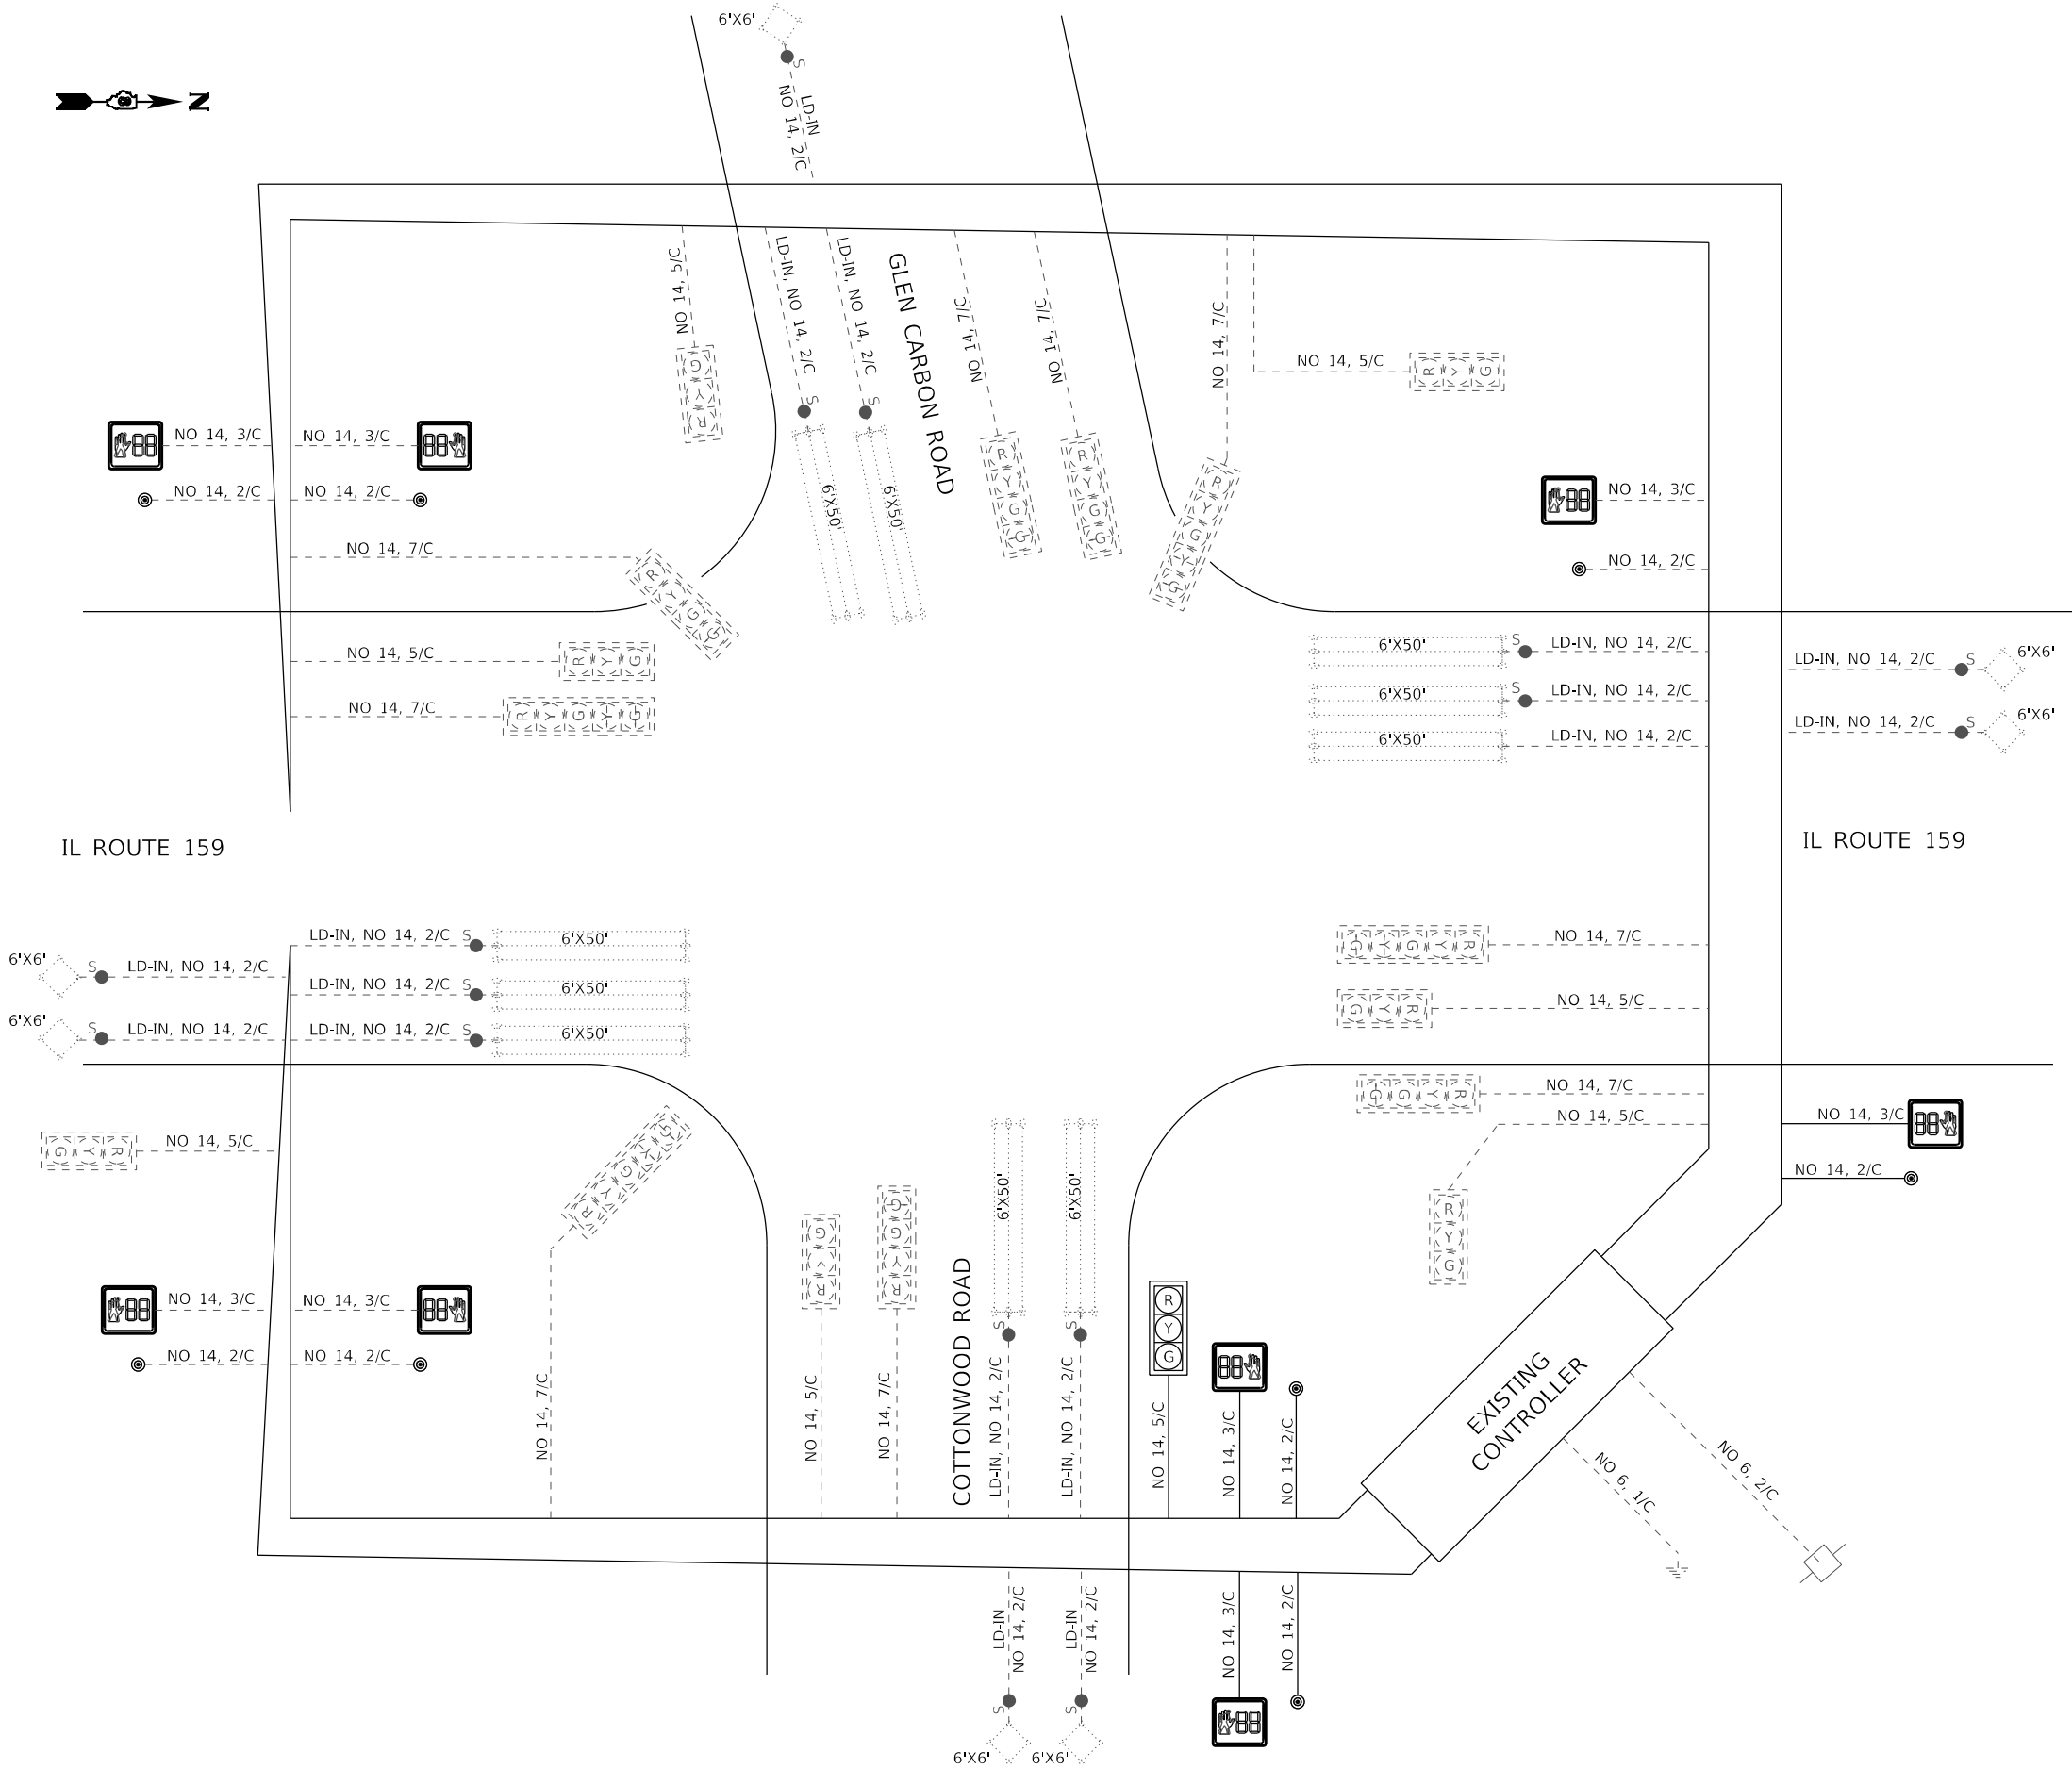

EXISTING TRAFFIC SIGNAL FACES

 


PEDESTRIAN PUSH BUTTON
WITH COUNTDOWN TIMER

PROPOSED TRAFFIC SIGNAL FACES

CABLE DIAGRAM LEGEND

- ⊙ PROPOSED PEDESTRIAN PUSH BUTTON
- PROPOSED ELECTRIC CABLE IN CONDUIT
- 2/C INDICATES NUMBER OF CONDUCTORS IN CABLE
- NO. 6 INDICATES AMERICAN WIRE (AWG) SIZE 6
- - - - EXISTING ELECTRIC CABLE IN CONDUIT
- ⊙ EXISTING PEDESTRIAN PUSH BUTTON
- EXISTING SERVICE INSTALLATION
- S CABLE SPLICE

MODEL: Default
FILE NAME: 1030066_10DOT.DWG
PLOT DATE: 6/30/2022
IL PROF DESIGN FIRM 184,000899

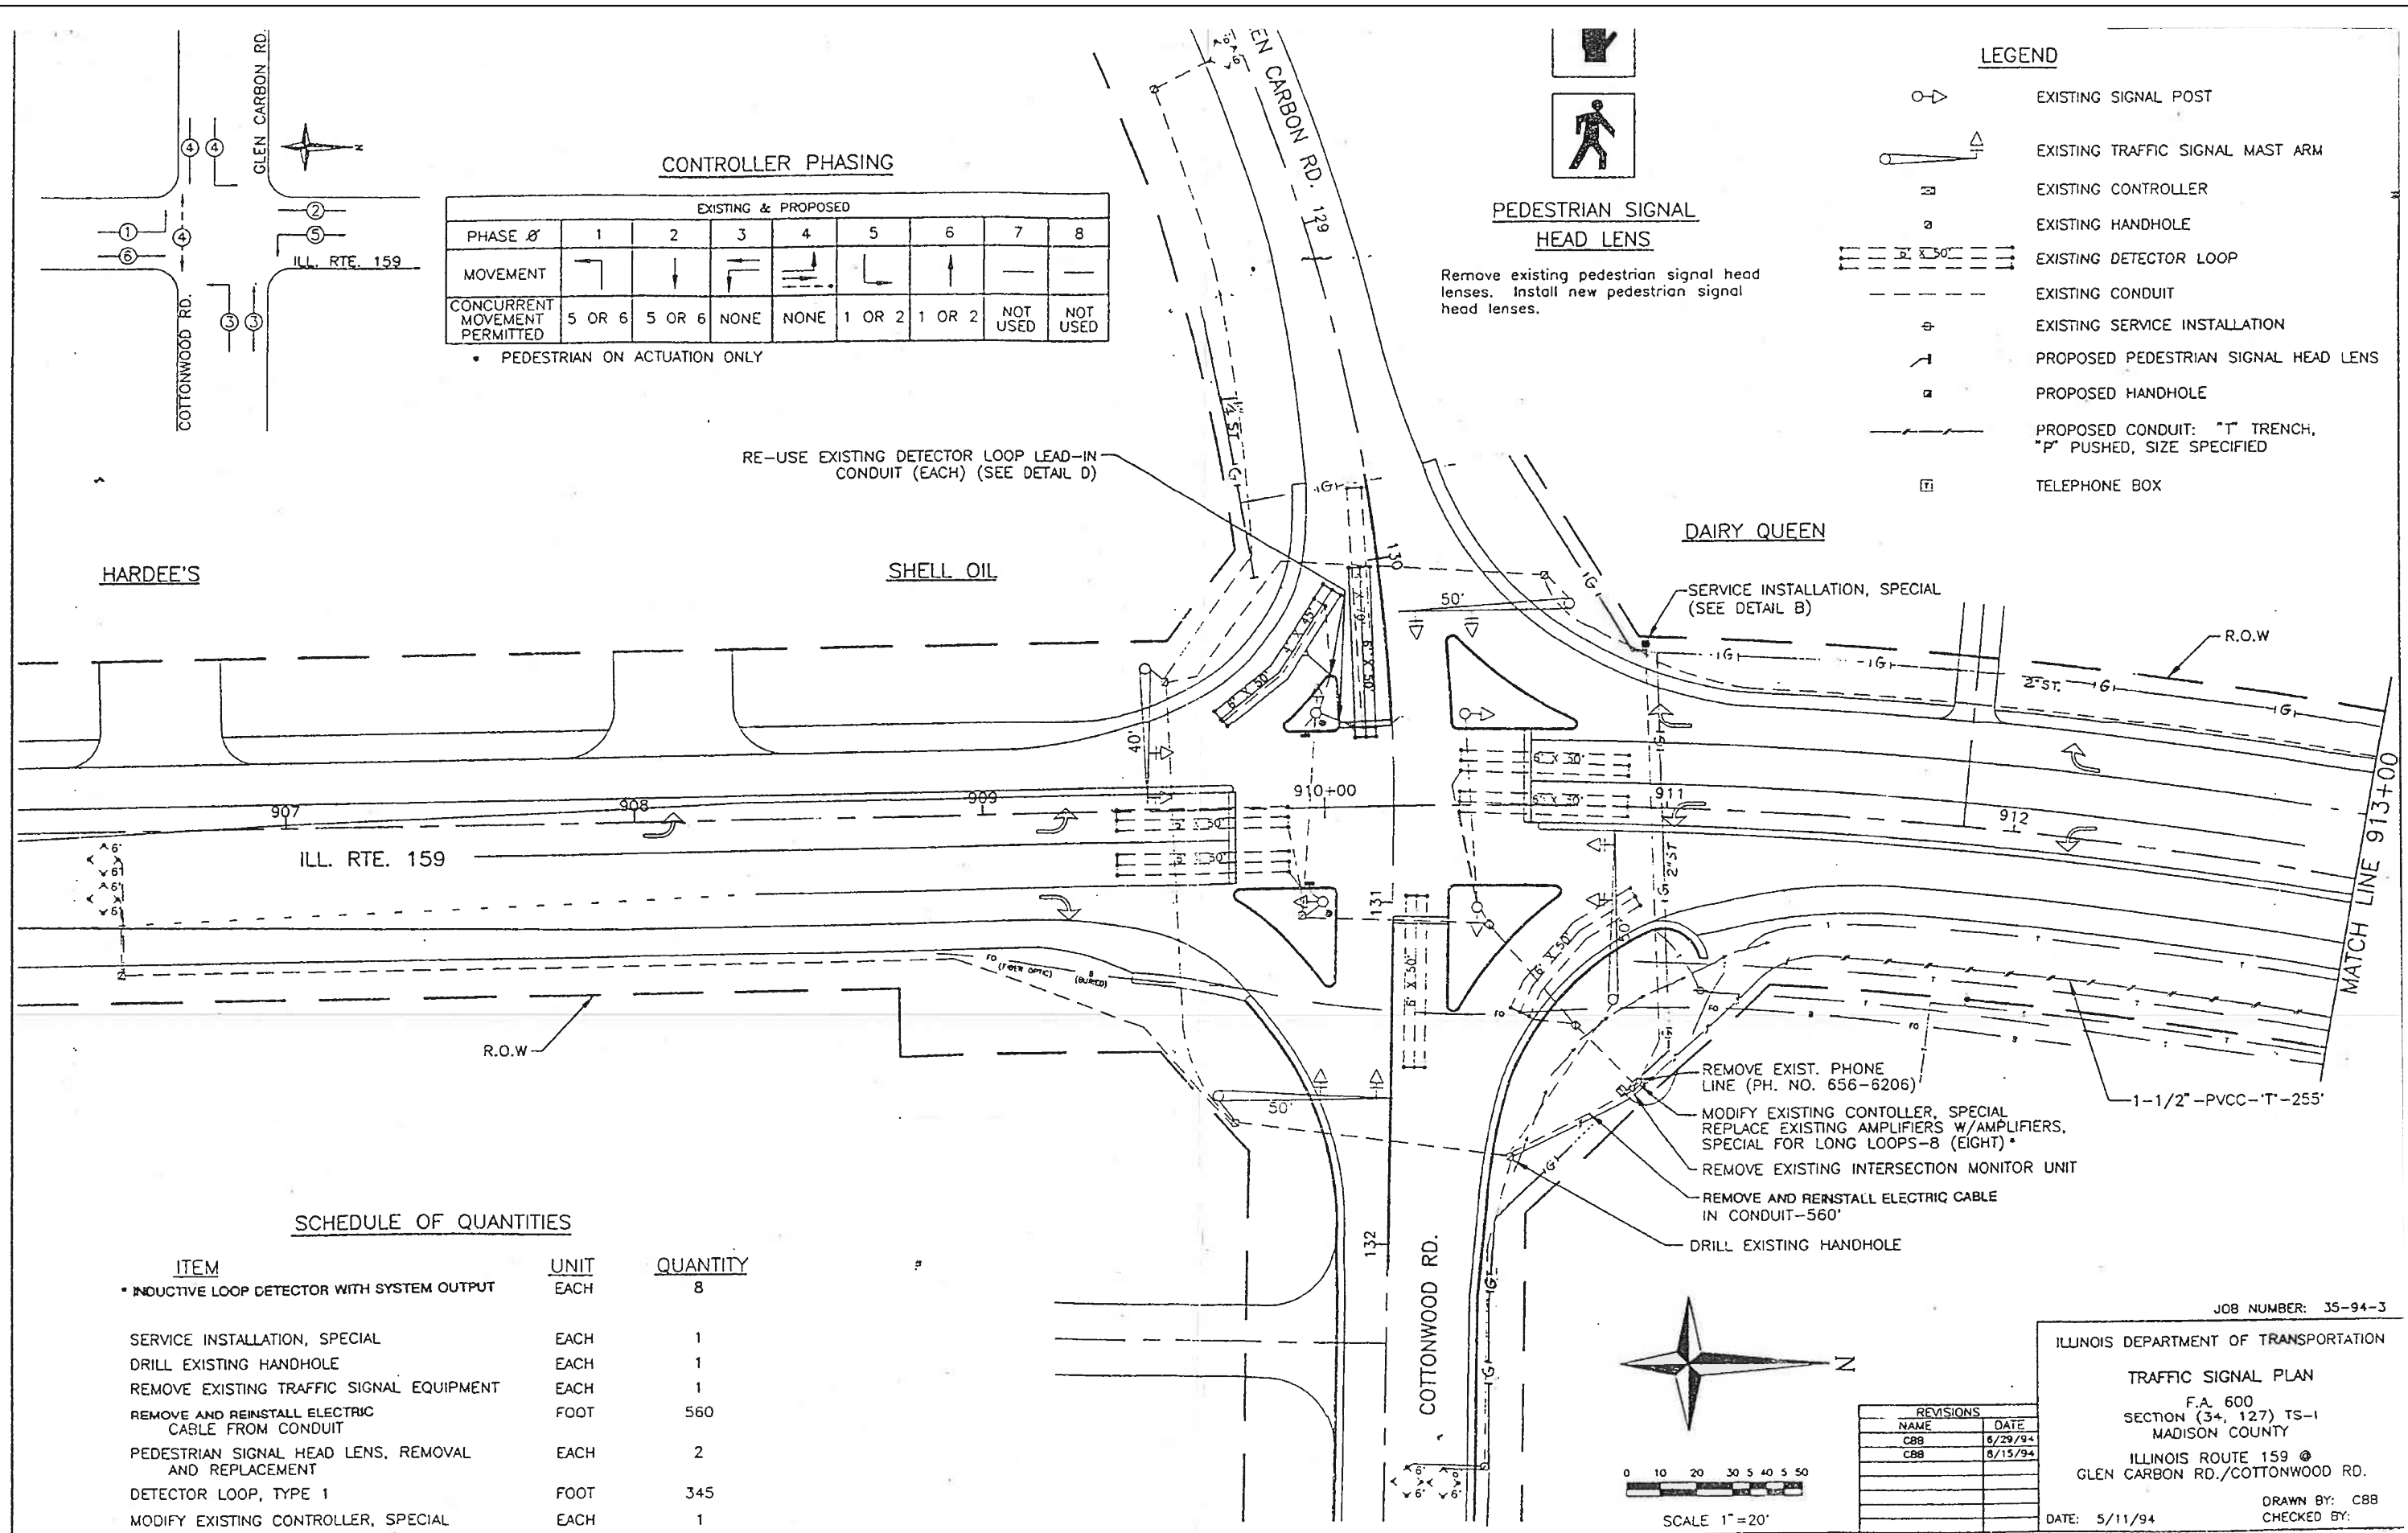

HMG
ENGINEERS
IL PROF DESIGN FIRM 184,000899

USER NAME = nseelhoefer
PLOT SCALE = 0.1667" / ft.
PLOT DATE = 6/30/2022

DESIGNED -
DRAWN -
CHECKED -
DATE -

REVISED -
REVISED -
REVISED -
REVISED -

STATE OF ILLINOIS
DEPARTMENT OF TRANSPORTATION

AS BUILT
IL ROUTE 159 & GLEN CARBON ROAD/COTTONWOOD ROAD
SCALE: SHEET OF SHEETS STA. TO STA.

FAU RTE	SECTION	COUNTY	TOTAL SHEETS	SHEET NO.
8887	(122,122-1,30)RS-4	MADISON	328	273A
CONTRACT NO. 76M87				

ILLINOIS FED. AID PROJECT

MODEL: Sheet 30 - Junction
FILE NAME: 188249_170_139_02218249_010.WD1_IL159_Traffic_Signal_Upgrade\Card_Sheets\0876M87-Cable_Diagrams.dgn



USER NAME	= nseelhoefer
PLOT SCALE	= 10,0000 ' / in.
PLOT DATE	= 6/30/2022

DESIGNED -	
DRAWN -	
CHECKED -	
DATE -	



REVISED -	
REVISED -	
REVISED -	
REVISED -	

STATE OF ILLINOIS
DEPARTMENT OF TRANSPORTATION


CABLE DIAGRAM
IL ROUTE 159 & JUNCTION DRIVE

SCALE: NTS SHEET TS 30 OF 31 SHEETS STA. TO STA.

F.A.P. RTE.	SECTION	COUNTY	TOTAL SHEETS	SHEET NO.
600	(122,122-1,30)RS-4	MADISON	328	275
CONTRACT NO. 76M87				
ILLINOIS FED. AID PROJECT				

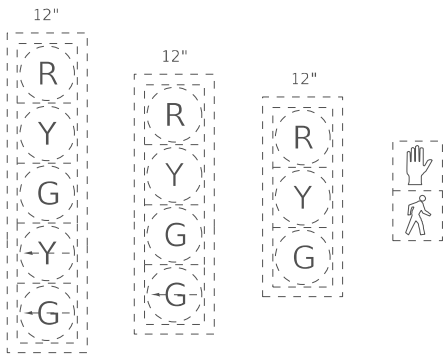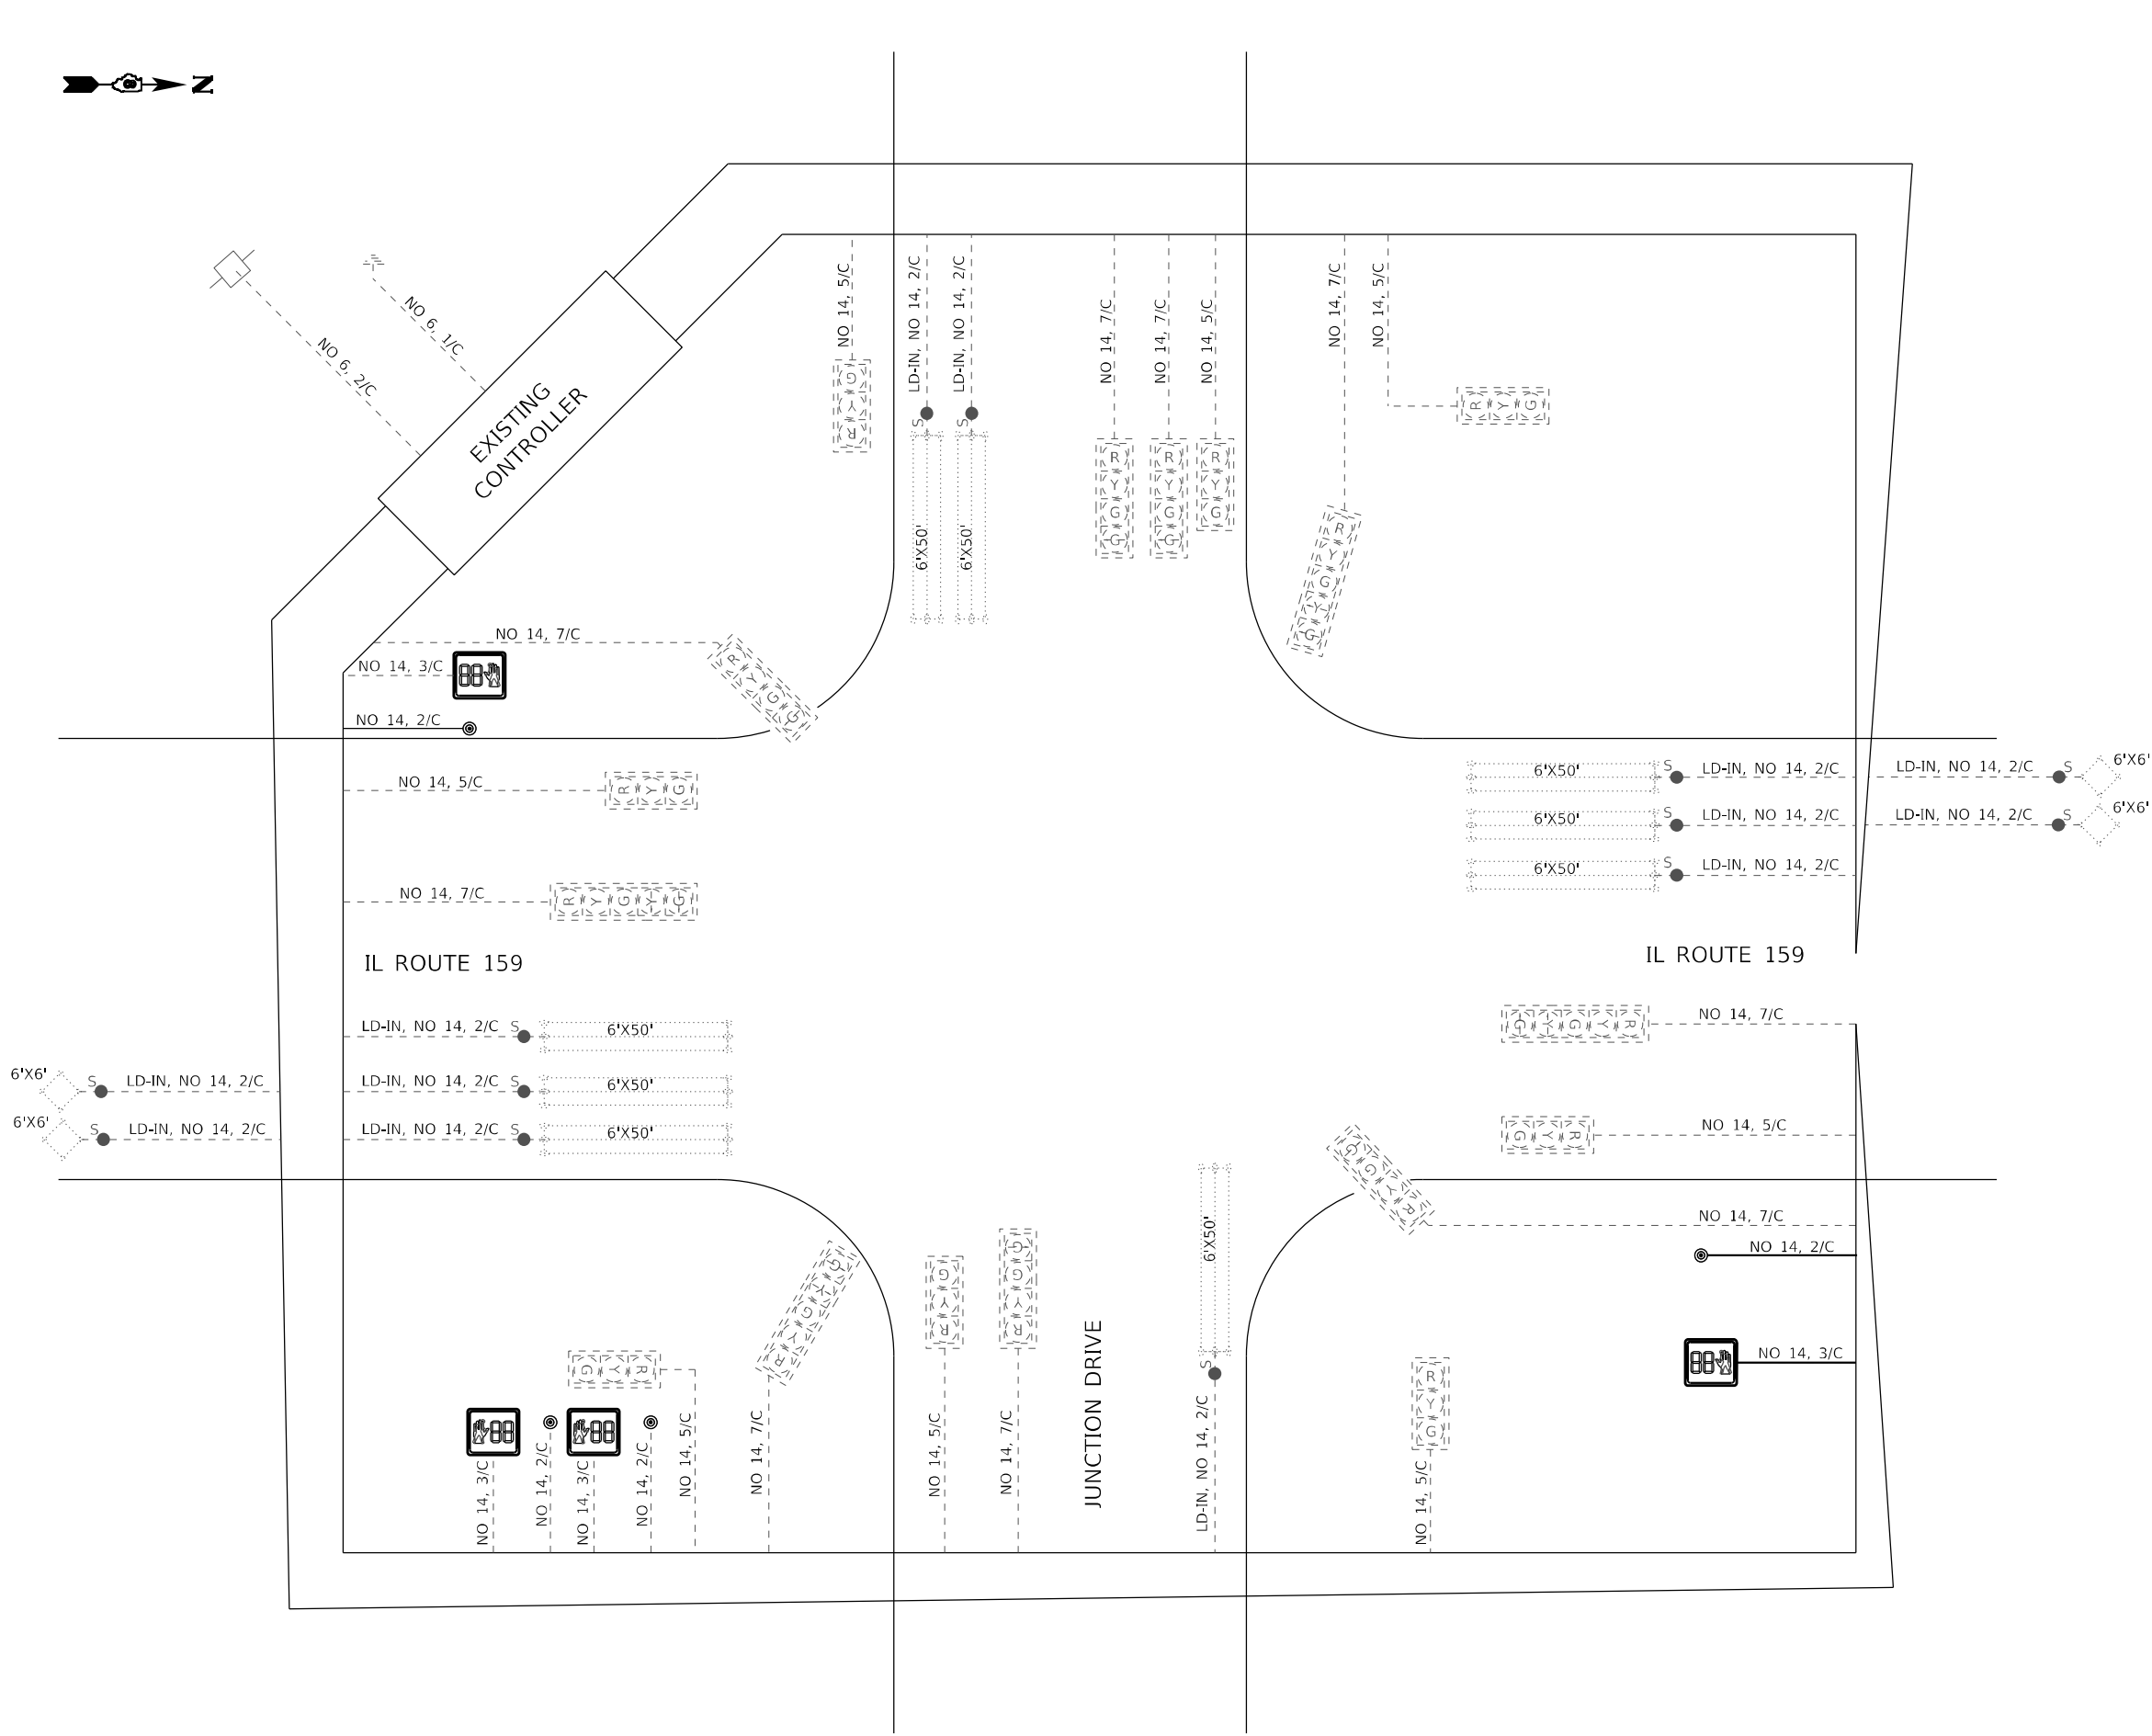


EXISTING TRAFFIC SIGNAL FACES

 

PEDESTRIAN PUSH BUTTON
WITH COUNTDOWN TIMER


PROPOSED TRAFFIC SIGNAL FACES

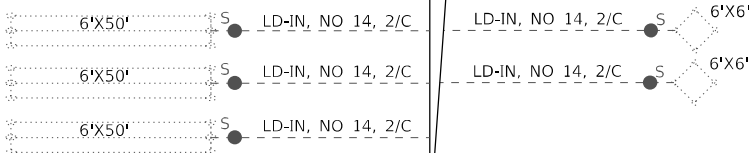


CABLE DIAGRAM LEGEND

- ⊙ PROPOSED PEDESTRIAN PUSH BUTTON
- PROPOSED ELECTRIC CABLE IN CONDUIT
- 2/C INDICATES NUMBER OF CONDUCTORS IN CABLE
- NO. 6 INDICATES AMERICAN WIRE (AWG) SIZE 6
- - - - EXISTING ELECTRIC CABLE IN CONDUIT
- ⊙ EXISTING PEDESTRIAN PUSH BUTTON
- EXISTING SERVICE INSTALLATION
- CABLE SPLICE

SECTION	COUNTY	TOTAL SHEETS	SHEET NO.
127-1R-3	MADISON	511	286
STA. 707+575 TO STA. 707+725			
EXISTING CONDITIONS:			

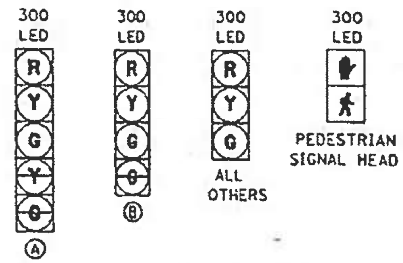




DETAIL E
NOT TO SCALE

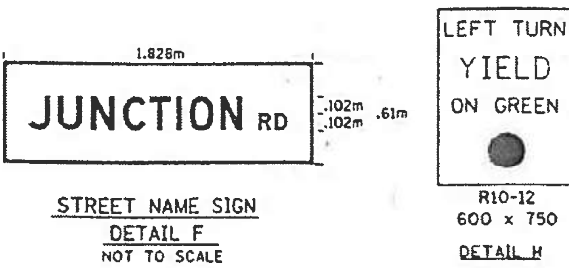

STREET NAME SIGN
DETAIL F
NOT TO SCALE

LEFT TURN
YIELD
ON GREEN
R10-12
600 x 750
DETAIL H

PROPOSED TRAFFIC
SIGNAL FACES

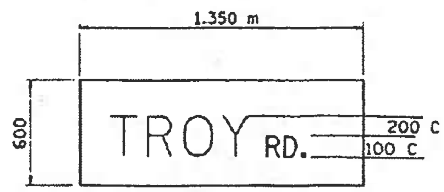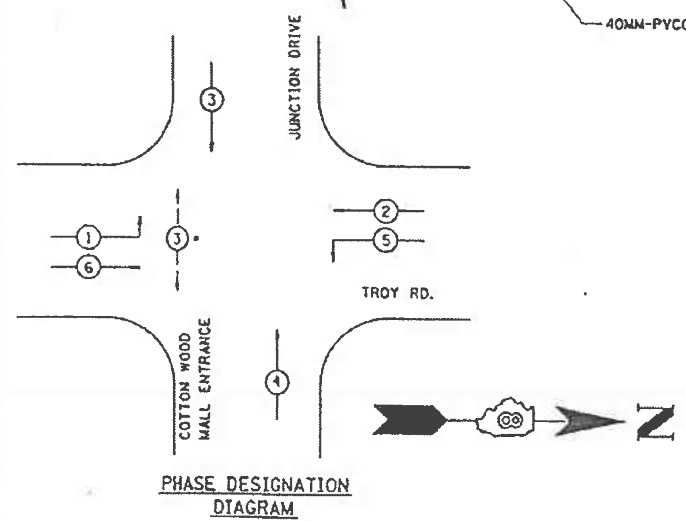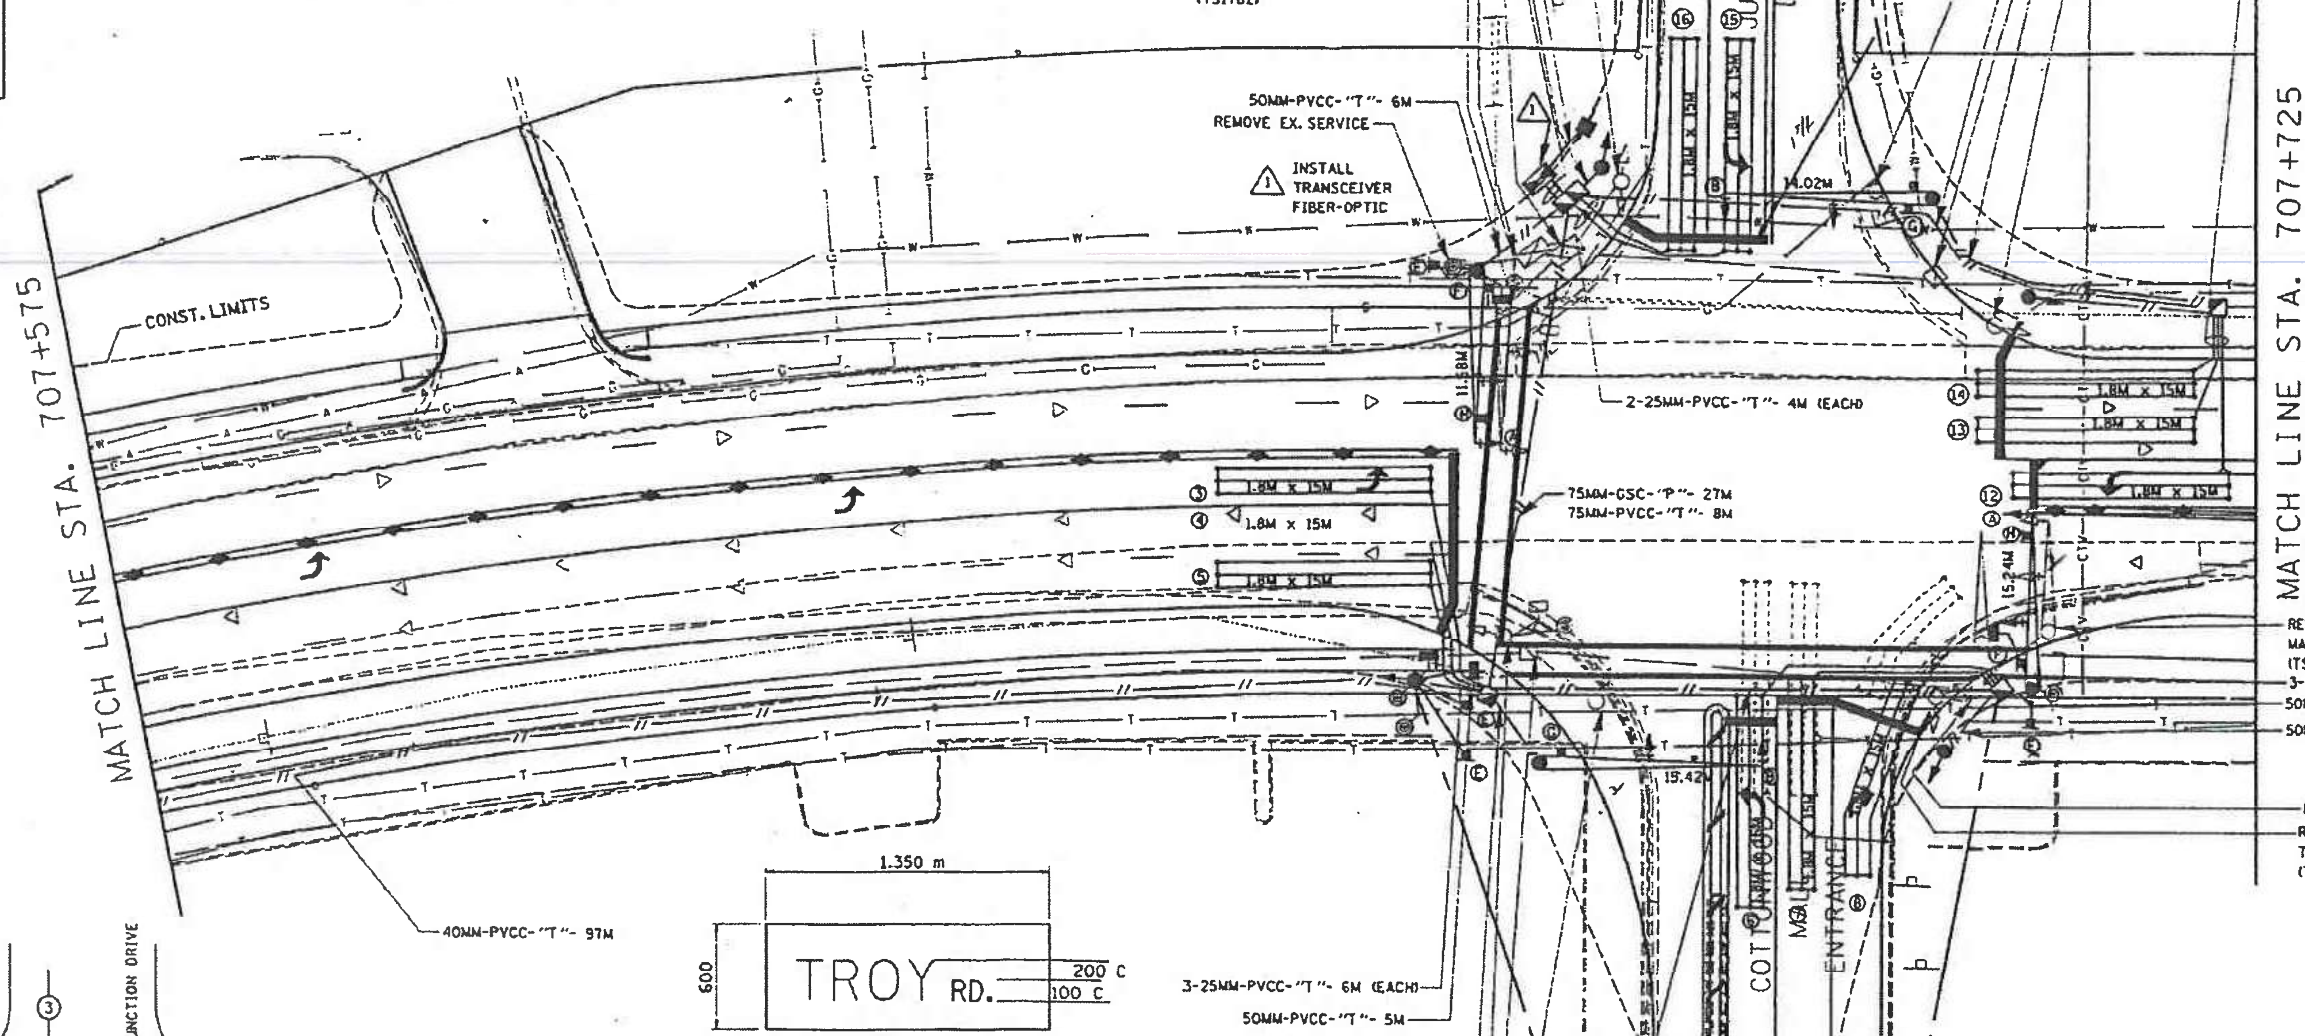


STREET NAME SIGN
DETAIL G
NOT TO SCALE

FULL-ACTUATED CONTROLLER
IN TYPE IV CABINET

EXISTING AND PROPOSED SEQUENCE OF OPERATION								
PHASE	1	2	3	4	5	6	7	8
MOVEMENT	NBLT	SB	EB	WB	SBLT	NB	NOT	NOT
CONCURRENT MOVEMENT PERMITTED	OR 5	OR 5	4	3	OR 1	OR 2	USED	USED

 • PEDESTRIAN SIGNAL ACTIVATION BY PUSHBUTTON ACTUATION, ONLY



ALL DIMENSIONS ARE IN MM
UNLESS DESIGNATED OTHERWISE

REVISIONS	
NAME	DATE

ILLINOIS DEPARTMENT OF TRANSPORTATION
JUNCTION RD./
COTTONWOOD MALL & TROY RD.
TRAFFIC SIGNAL PLAN

FAP 600 ROUTE
SECTION 127-1R-3
MADISON COUNTY
DRAWN BY:

MODEL: Default
FILE NAME: 103066_100T_D448_P18194_05190606_010_W011_IL1591Design007648724dr-48481111.dgn

HMG
ENGINEERS
IL PROF DESIGN FIRM 184,000899

USER NAME = nseelhoefer	DESIGNED -	REVISED -
PLOT SCALE = 0.1667" / 1'	DRAWN -	REVISED -
PLOT DATE = 6/30/2022	CHECKED -	REVISED -
	DATE -	REVISED -

STATE OF ILLINOIS
DEPARTMENT OF TRANSPORTATION

AS BUILT
IL ROUTE 159 & JUNCTION DRIVE

SCALE: SHEET OF SHEETS STA. TO STA.

FAU RTE	SECTION	COUNTY	TOTAL SHEETS	SHEET NO.
8887	(122,122-1,30)RS-4	MADISON	328	275A
				CONTRACT NO. 76M87
ILLINOIS FED. AID PROJECT				



- NOTES:**
- (A) EXISTING SIGNAL HEAD WITH BACKPLATE TO BE RELOCATED
 - (B) ACCESSIBLE PED SIGNAL SIGN R10-3e

MODEL: Sheet 16 - Illini
FILE NAME: 108249_17B_199_03282919_010_W01_IL159_Traffic_Signal_Upgrade.dgn
108249_17B_199_03282919_010_W01_IL159_Traffic_Signal_Upgrade.dgn

HMG
ENGINEERS
IL PROF DESIGN FIRM 184,000899

USER NAME = nseelhoefer	DESIGNED -	REVISED -
	DRAWN -	REVISED -
PLOT SCALE = 20,000' / in.	CHECKED -	REVISED -
PLOT DATE = 6/30/2022	DATE -	REVISED -











STATE OF ILLINOIS
DEPARTMENT OF TRANSPORTATION

TRAFFIC SIGNAL PLANS
IL ROUTE 159 & ILLINI DRIVE


SCALE: 1" = 10' SHEET TS 16 OF 31 SHEETS STA. TO STA.

F.A.P. RTE.	SECTION	COUNTY	TOTAL SHEETS	SHEET NO.
600	(122,122-1,30)RS-4	MADISON	328	276
CONTRACT NO. 76M87				
ILLINOIS FED. AID PROJECT				

 MODEL: Sheet 31 - ILLI
FILE NAME: 108246_770_199_02218249_010_W01_IL159_Traffic_Signal_Upgrade\Card_Sheets\0876M87-Cable_Diagram.dgn

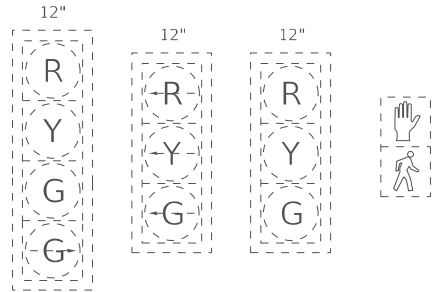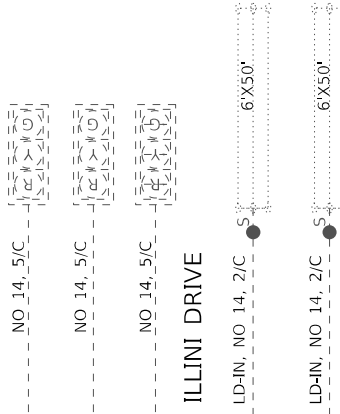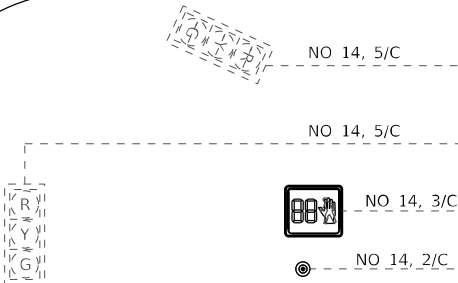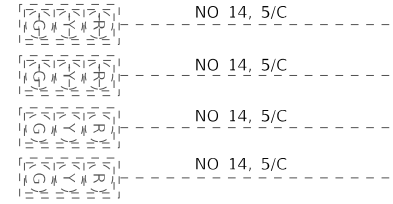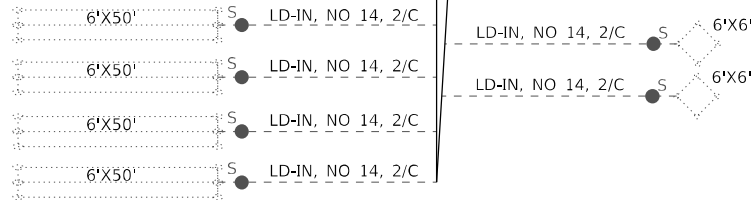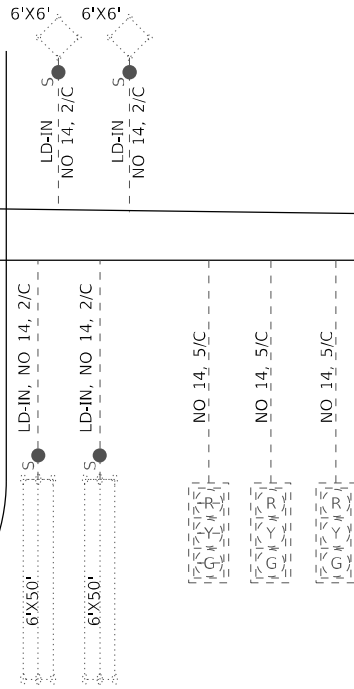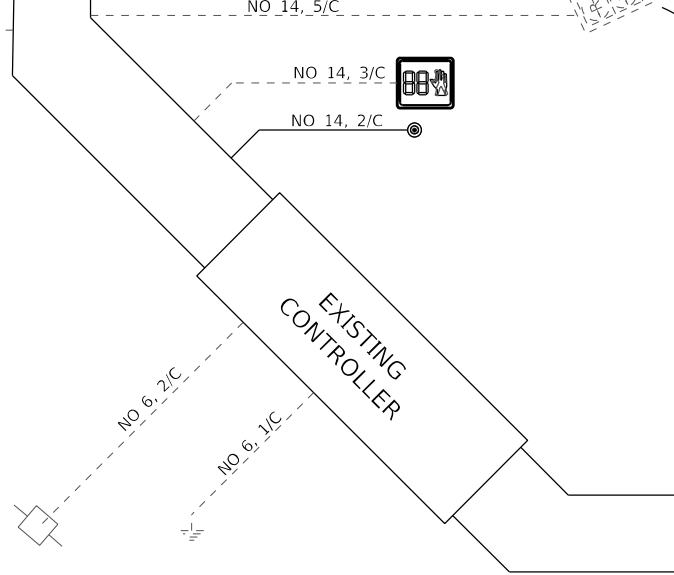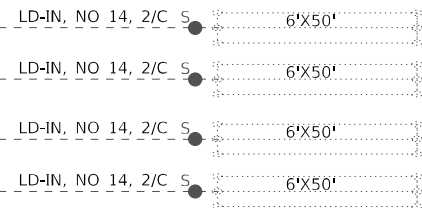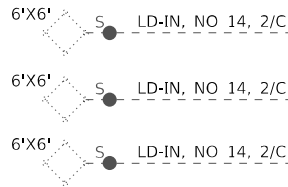

EXISTING TRAFFIC SIGNAL FACES

 

PEDESTRIAN PUSH BUTTON
WITH COUNTDOWN TIMER

PROPOSED TRAFFIC SIGNAL FACES

CABLE DIAGRAM LEGEND

- ⊙ PROPOSED PEDESTRIAN PUSH BUTTON
- PROPOSED ELECTRIC CABLE IN CONDUIT
- 2/C INDICATES NUMBER OF CONDUCTORS IN CABLE
- NO. 6 INDICATES AMERICAN WIRE (AWG) SIZE 6
- - - - EXISTING ELECTRIC CABLE IN CONDUIT
- ⊙ EXISTING PEDESTRIAN PUSH BUTTON
- EXISTING SERVICE INSTALLATION
- S CABLE SPLICE



USER NAME = nseelhoefer
PLOT SCALE = 10,000' / in.
PLOT DATE = 6/30/2022

DESIGNED -
DRAWN -
CHECKED -
DATE -


REVISED -
REVISED -
REVISED -
REVISED -

STATE OF ILLINOIS
DEPARTMENT OF TRANSPORTATION





CABLE DIAGRAM
IL ROUTE 159 & ILLINI DRIVE

SCALE: NTS SHEET TS 31 OF 31 SHEETS TO STA. TO STA.

F.A.P. RTE.	SECTION	COUNTY	TOTAL SHEETS	SHEET NO.
600	(122,122-1,30)RS-4	MADISON	328	277
CONTRACT NO. 76M87				
ILLINOIS FED. AID PROJECT				

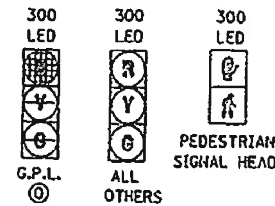


MATCH LINE
STA. 1+125

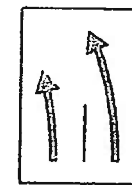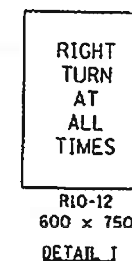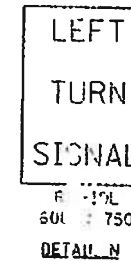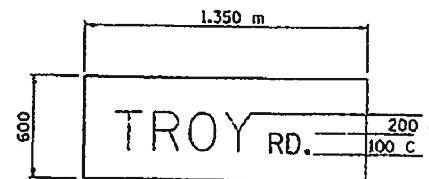

FAU	SECTION	COUNTY	TOTAL SHEETS	SHEET NO.
600	127-IR-3	MADISON	328	269
STA. 707+900 TO STA. 708+075				

EXISTING CONDITIONS

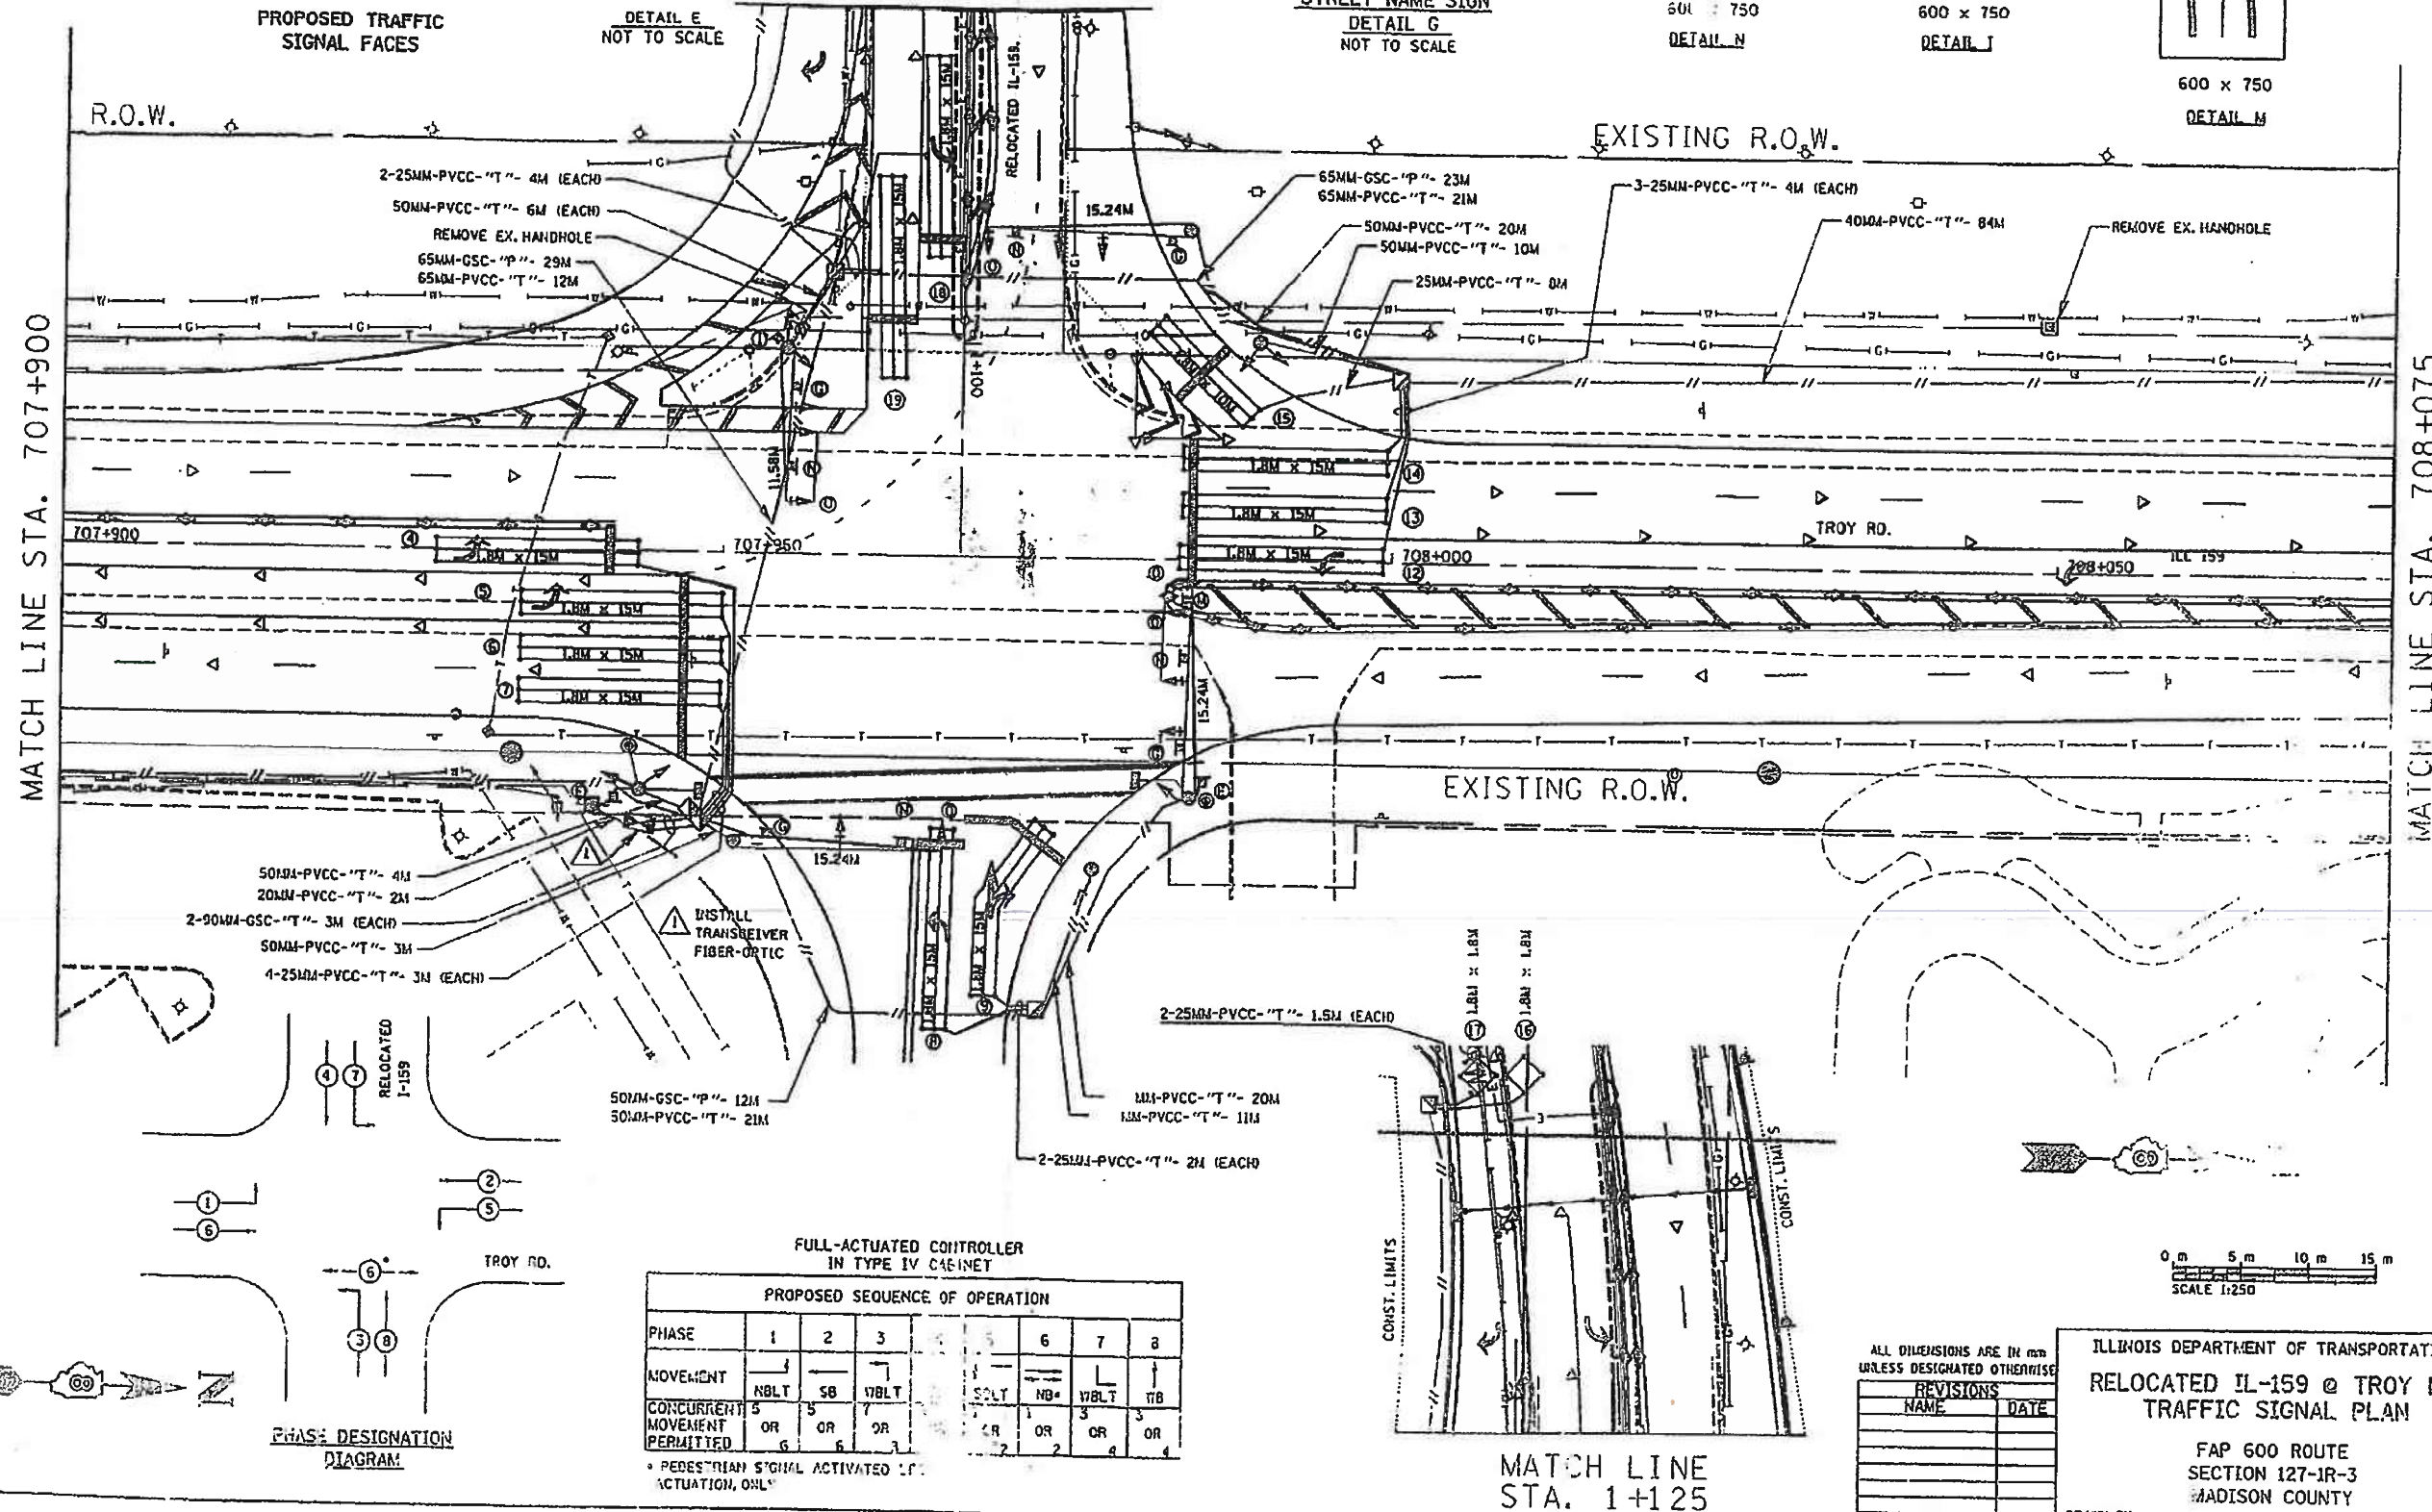

FULL-ACTUATED CONTROLLER
IN TYPE IV CABINET

PROPOSED SEQUENCE OF OPERATION							
PHASE	1	2	3	4	5	6	7
MOVEMENT	NBLT	SB	NBLT	SB	NBLT	SB	NBLT
CONCURRENT MOVEMENT PERMITTED	OR	OR	OR	OR	OR	OR	OR

PEDESTRIAN SIGNAL ACTIVATED 1.0" ACTUATION, ORL

ALL DIMENSIONS ARE IN MM
UNLESS DESIGNATED OTHERWISE

REVISIONS	NAME	DATE

ILLINOIS DEPARTMENT OF TRANSPORTATION
RELOCATED IL-159 @ TROY RD.
TRAFFIC SIGNAL PLAN

FAP 600 ROUTE
SECTION 127-IR-3
MADISON COUNTY

DRAWN BY:

HMG
ENGINEERS

USER NAME = nseelhoefer
PLOT SCALE = 0.1667" / 1"
PLOT DATE = 6/30/2022

DESIGNED -
DRAWN -
CHECKED -
DATE -

REVISED -
REVISED -
REVISED -
REVISED -

STATE OF ILLINOIS
DEPARTMENT OF TRANSPORTATION

AS BUILT
IL ROUTE 159 & ILLINI DRIVE

SCALE: SHEET OF SHEETS STA. TO STA.

FAU	SECTION	COUNTY	TOTAL SHEETS	SHEET NO.
8887	(122,122-1,30)RS-4	MADISON	328	277A
CONTRACT NO. 76M87				

ILLINOIS FED. AID PROJECT

Page 1 of 1

Date 3/9/10

STRUCT. NO.	N/A	D	B	U	M	O	S	Surface Water Elev.		ft
Station	N/A	E	L	C				Stream Bed Elev.		ft
BORING NO.	1 SE Quad	P	O	S	I	T		Groundwater Elev.:		
Station	589+22	H	S	Qu				First Encounter	548.6	ft ▼
Offset	84.0 ft Right							Upon Completion		ft
Ground Surface Elev.	557.60	ft	(ft)	(/6")	(tsf)	(%)		After Hrs.		ft

[illegible]

BBS, form 137 (Rev. 8-99)

Page 1 of 1

Date 3/9/10

STRUCT. NO. _____	N/A	D E P T H	B L O W S	U C S	M O I S T	Surface Water Elev. _____	ft	
Station _____	N/A					Stream Bed Elev. _____	ft	
BORING NO. _____	2 NE Quad					Groundwater Elev.: _____		
Station _____	589+94					First Encounter _____	ft	
Offset _____	63.0 ft Right			Upon Completion _____	ft			
Ground Surface Elev. _____	556.10	ft	(ft)	(/6")	(tsf)	(%)	After _____ Hrs. _____	ft

			1.3	25	
Brown Silty Clay LOAM A-6(9) See Classification @ 5 ft			2.0	28	
			2.5	29	
			2.5	29	
			2.3	34	
	-5		2.0	31	
			1.5	32	
Gray	549.10				
Refusal in Unsuitable Material - END OF HAND AUGER					
Pocket Penetrometer used for Qu End of Boring	-10				
	-15				
	-20				

BBS, form 137 (Rev. 8-99)



**Illinois Department
of Transportation**
Division of Highways
Illinois Department of Transportation

SOIL BORING LOG

Page 1 of 1

Date 3/9/10

ROUTE FAP 600 DESCRIPTION Traffic Signals at IL 159 and Beltline in Collinsville LOGGED BY JH & CH

SECTION 60-(30,31,128)-N LOCATION S 1/2, SEC. 22, TWP. 3N, RNG. 8W, 3rd PM.
Latitude , Longitude

COUNTY Madison DRILLING METHOD Hand Auger HAMMER TYPE

STRUCT. NO. N/A
Station N/A
BORING NO. 3 NW Quad
Station 589+55
Offset 61.0 ft Left
Ground Surface Elev. 561.20 ft

DEPTH T H (ft)	BLOW S W (/6")	UCS Qu (tsf)	MOIST T (%)
		1.5	23
		1.5	21
		2.0	26
		2.0	28
		2.5	27
-5		2.3	30
		1.8	30
		1.8	31
		1.8	30
		2.0	31
-10		2.0	30
		2.0	30
		2.3	31

Surface Water Elev. _____ ft
Stream Bed Elev. _____ ft
Groundwater Elev.: _____ ft
First Encounter 551.2 ft
Upon Completion _____ ft
After _____ Hrs. _____ ft

Dark Brown Silty LOAM
A-4(8)
See Classification @ 5 ft

Light Brown 566.20

Light Brown and Gray SILT
A-6(8)
See Classification @ 10 ft

Light Brown

Mottled

Gray

END OF HAND AUGER

Pocket Penetrometer used for
Qu
End of Boring

The Unconfined Compressive Strength (UCS) Failure Mode is indicated by (B-Bulge, S-Shear, P-Penetrometer)
The SPT (N value) is the sum of the last two blow values in each sampling zone (AASHTO T206)

BBS, form 137 (Rev. 8-99)



**Illinois Department
of Transportation**
Division of Highways
Illinois Department of Transportation

SOIL BORING LOG

Page 1 of 1

Date 3/26/10

ROUTE FAP 600 DESCRIPTION Traffic Signals at IL 159 and Beltline in Collinsville LOGGED BY VPG & CH

SECTION 60-(30,31,128)-N LOCATION S 1/2, SEC. 22, TWP. 3N, RNG. 8W, 3rd PM.
Latitude , Longitude

COUNTY Madison DRILLING METHOD Hand Auger HAMMER TYPE

STRUCT. NO. N/A
Station N/A
BORING NO. 4 SW Quad
Station 588+59
Offset 41.0 ft Left
Ground Surface Elev. 559.50 ft

DEPTH T H (ft)	BLOW S W (/6")	UCS Qu (tsf)	MOIST T (%)
		NS	
		NS	
		1.5	
		0.8	33
		0.8	
-5		0.5	
		0.3	30
		0.3	
		0.5	
		0.5	
549.50 -10		0.8	32
		1.0	29
		1.5	

Surface Water Elev. _____ ft
Stream Bed Elev. _____ ft
Groundwater Elev.: _____ ft
First Encounter 555.5 ft
Upon Completion _____ ft
After _____ Hrs. _____ ft

11" Top Soil & 0" PCC
557.50

Medium Brown Silty Clay LOAM
A-3(12)
See Classification @ 3 ft

Light Brown SILT
A-4(0)
See Classification @ 6 ft

Light Brown SILT
A-3(8)
See Classification @ 10 ft
Light Gray with Black SILT
A-4(8)
See Classification @ 11 ft

END OF HAND AUGER

Pocket Penetrometer used for
Qu
End of Boring

The Unconfined Compressive Strength (UCS) Failure Mode is indicated by (B-Bulge, S-Shear, P-Penetrometer)
The SPT (N value) is the sum of the last two blow values in each sampling zone (AASHTO T206)

BBS, form 137 (Rev. 8-99)

MODEL Default
FILE NAME: I:\03066\DOT\Draws\RTB\194_0518066_010_WC1_IL159CAD_Sheets\0876M87-cht-BoringSheets.dgn

HMG
ENGINEERS

IL PROF DESIGN FIRM 184,000899

USER NAME = nseelhoefer

DESIGNED -

REVISED -

DRAWN -

REVISED -

PLOT SCALE = 10,000' / in.

CHECKED -

REVISED -

PLOT DATE = 6/30/2022

DATE -

REVISED -

**STATE OF ILLINOIS
DEPARTMENT OF TRANSPORTATION**

**IL 159 & BELTLINE ROAD
SOIL BORINGS**

SCALE: SHEET OF SHEETS STA. TO STA.

FAU
RTE

SECTION

COUNTY

TOTAL
SHEETS

SHEET
NO.

8887

(122,122-1,30)RS-4

MADISON

328

279

CONTRACT NO. 76M87

ILLINOIS FED. AID PROJECT



Page 1 of 1

Date 3/10/10

ROUTE	<u>FAP 600</u>	DESCRIPTION	<u>Traffic Signals at IL 159 and Beltline in Collinsville</u>	LOGGED BY	<u>C. Higgins</u>
--------------	----------------	--------------------	---	------------------	-------------------

SECTION 60-(30,31,128)-N **LOCATION** S 1/2, SEC. 22, TWP. 3N, RNG. 8W, 3rd PM,

COUNTY Madison DRILLING METHOD Hand Auger HAMMER TYPE _____

STRUCT. NO. _____ N/A
Station _____ N/A

BORING NO. 5 Ramp
Station 589+41
Offset 139.0 ft Left
Ground Surface Elev. 561.00

D E P T H	B L O W S	U C S Qu	M O I S T
(ft)	(/6")	(tsf)	(%)

Surface Water Elev. _____ ft
Stream Bed Elev. _____ ft

Groundwater Elev.:
First Encounter _____ 553.0 ft
Upon Completion _____ ft
After _____ Hrs. _____ ft

[illegible]

The Unconfined Compressive Strength (UCS) Failure Mode is indicated by (B-Bulge, S-Shear, P-Penetrometer)
The SPT (N value) is the sum of the last two blow values in each sampling zone (AASHTO T206)



Illinois Department
of Transportation
Division of Highways
Illinois Department of Transportation

SOIL BORING LOG

Page 1 of 1

Date 9/12/05

ROUTE FAP 600 DESCRIPTION Traffic Signals at IL 159 and Camelot in Collinsville LOGGED BY reader / Warlick

SECTION 30-1TS-1 LOCATION NE 1/4, SE 1/4, SEC. 22, TWP. 3N, RNG. 8W, 3rd PM, Latitude , Longitude

COUNTY Madison DRILLING METHOD Hollow Stem Auger HAMMER TYPE 140# Automatic

STRUCT. NO. Station BORING NO. SB #3 SE Quad Station 609+63 Offset 52.5 ft Left Ground Surface Elev. 561.76

DEPTH	BLOWS	UCS	MOST	Surface Water Elev.	Stream Bed Elev.	Groundwater Elev.:	First Encounter	Upon Completion	After Hrs.
ft	(ft)	(/6")	(tsf)	(%)	ft	ft	ft	ft	ft

Brown Silty LOAM

4
7
9
4.0
P
16

-5
4
3
3.0
P
21

3
2
2
0.8
S/20
42

-10
2
5
1.2
S/20
27

550.76

End of Boring
End of Boring

The Unconfined Compressive Strength (UCS) Failure Mode is indicated by (B-Bulge, S-Shear, P-Penetrometer)
The SPT (N value) is the sum of the last two blow values in each sampling zone (AASHTO T206)
BBS, form 137 (Rev. 8-99)



Illinois Department
of Transportation
Division of Highways
Illinois Department of Transportation

SOIL BORING LOG

Page 1 of 1

Date 9/12/05

ROUTE FAP 600 DESCRIPTION Traffic Signals at IL 159 and Camelot in Collinsville LOGGED BY amaro / Warlick

SECTION 30-1TS-1 LOCATION NE 1/4, SE 1/4, SEC. 22, TWP. 3N, RNG. 8W, 3rd PM, Latitude , Longitude

COUNTY Madison DRILLING METHOD Hollow Stem Auger HAMMER TYPE 140# Automatic

STRUCT. NO. Station BORING NO. SB #4 NE Quad Station 610+32 Offset 55.0 ft Left Ground Surface Elev. 561.70

DEPTH	BLOWS	UCS	MOST	Surface Water Elev.	Stream Bed Elev.	Groundwater Elev.:	First Encounter	Upon Completion	After Hrs.
ft	(ft)	(/6")	(tsf)	(%)	ft	ft	ft	ft	ft

Brown Silty LOAM

6
6
7
1.8
P
10

-5
5
6
4.5
P
12

554.76

Brown Silty Clay LOAM

3
3
5
3.5
S/15
18

-10
2
3
1.3
S/20
24

550.76

End of Boring
End of Boring

The Unconfined Compressive Strength (UCS) Failure Mode is indicated by (B-Bulge, S-Shear, P-Penetrometer)
The SPT (N value) is the sum of the last two blow values in each sampling zone (AASHTO T206)
BBS, form 137 (Rev. 8-99)

MODEL Default
FILE NAME: 103066_10DOT_D1618_P181194_05918066_0.10_WC1_IL159(CAD_Sheets)0876M87-4ht-BoringSheets.dgn

HMG
ENGINEERS

IL PROF DESIGN FIRM 184,000899

USER NAME = nseelhoefer

DESIGNED -

REVISED -

DRAWN -

REVISED -

PLOT SCALE = 10,0000 ' / in.

CHECKED -

REVISED -

PLOT DATE = 6/30/2022

DATE -

REVISED -

STATE OF ILLINOIS
DEPARTMENT OF TRANSPORTATION

IL 159 & CAMELOT DRIVE
SOIL BORINGS

SCALE: SHEET OF SHEETS STA. TO STA.

FAU

RTE

SECTION

COUNTY

TOTAL

SHEETS

SHEET

NO.

8887

(122,122-1,30)RS-4

MADISON

328

282

CONTRACT NO. 76M87

ILLINOIS FED. AID PROJECT



Page 1 of 1

Date 4/11/90

ROUTE	FAP 600	DESCRIPTION	LOGGED BY
		Carbon Roads	Larry Ford

SECTION 127-1R-3, (34-1)-1 LOCATION NW 1/4, SEC. 26, TWP. 4N, RNG. 8W, 3rd PM, _____
Latitude , Longitude _____

COUNTY	Madison	DRILLING METHOD	Hollow Stem Auger	HAMMER TYPE	Automatic 140#
---------------	---------	------------------------	-------------------	--------------------	----------------

STRUCT. NO. _____	D	B	U	M	Surface Water Elev. _____	m	D	B	U	M
Station _____	E	L	C	O	Stream Bed Elev. _____	m	E	L	C	O
	P	L	S	I			P	L	S	I
BORING NO. #1 SE Quad	T	W	Q	T	Groundwater Elev.: _____	m	T	W	Q	T
Station 707+368	H	S	Qu		First Encounter _____	m	H	S	Qu	
Offset 25.60 m Right		(mm)	(kPa)	(%)	Upon Completion _____	m		(mm)	(kPa)	(%)
Ground Surface Elev. 175.20	m	(mm)	(kPa)	(%)	After Hrs. _____	m		(mm)	(kPa)	(%)

				Gray and Brown SILTY CLAY <i>(continued)</i>	1	86	26
					3	S/10	
					4		
Gray SILTY CLAY				168.80			
	1			End of Boring			
	1	67	25	End of Boring			
	2	S/10					
-1.5	1				-7.5		
	1	36	30				
	1	S/10					
----- 173.22							
Brown and Gray Very SILTY CLAY	1						
	1	29	32				
	1	S/10					
-3.0	1				-9.0		
	2	67	28				
	2	S					
	1						
	3	67	29				
	6	S/15					
----- 170.93							
Gray and Brown SILTY CLAY	-4.5	1			-10.5		
	4	125	28				
	4	S/10					
	1						
	2	57	26				
	4	S/15					
-6.0					-12.0		

The Unconfined Compressive Strength (UCS) Failure Mode is indicated by (B-Bulge, S-Shear, P-Penetrometer)
The SPT (N value) is the sum of the last two blow values in each sampling zone (AASHTO T206)

BBS, form 137 (Rev. 8-99)



Page 1 of 1

Date 4/11/90

ROUTE	FAP 600	DESCRIPTION	Carbon Roads	LOGGED BY
				Larry Ford

SECTION	127-1R-3, (34-1)-1	LOCATION	NW 1/4, SEC. 26, TWP. 4N, RNG. 8W, 3 rd PM, Latitude , Longitude
----------------	--------------------	-----------------	--

COUNTY Madison **DRILLING METHOD** Hollow Stem Auger **HAMMER TYPE** Automatic 140#

STRUCT. NO. _____	D	B	U	M	Surface Water Elev. _____ m	D	B	U	M
Station _____	E	L	C	O	Stream Bed Elev. _____ m	E	L	C	O
	P	O	S	I		P	O	S	I
BORING NO. #2 NE Quad	H	W	Qu	T	Groundwater Elev.: _____ m	H	W	Qu	T
Station 707+403					First Encounter _____ m				
Offset 12.50 m Right		(1/150			Upon Completion 173.3 m		(1/150		
Ground Surface Elev. 175.44 m	(m)	mm)	(kPa)	(%)	After _____ m	(m)	mm)	(kPa)	(%)

[illegible]

The Unconfined Compressive Strength (UCS) Failure Mode is indicated by (B-Bulge, S-Shear, P-Penetrometer)
The SPT (N value) is the sum of the last two blow values in each sampling zone (AASHTO T206)

BBS, form 137 (Rev. 8-99)

MODEL Default
FILE NAME: I:\03066\DOT\Draws\RTB\194_059\066_0.10_WC1 IL 159\CAD_Sheets\0876M87-shl-BoringSheets.dgn



**Illinois Department
of Transportation**
Division of Highways
Illinois Department of Transportation

SOIL BORING LOG

Page 1 of 1

Date _____

ROUTE FAP 600 DESCRIPTION Environmental Testing (Traffic Signals at IL 159 and Glen Carbon Road) LOGGED BY _____

SECTION 127-1R-3, (34-1)-1 LOCATION SW corner, SEC. , TWP. , RNG. ,
Latitude , Longitude

COUNTY Madison DRILLING METHOD Hollow Stem Auger HAMMER TYPE Automatic 140#

STRUCT. NO. _____	D	B	U	M	Surface Water Elev. _____ m				
Station _____	E	L	C	O	Stream Bed Elev. _____ m				
	P	O	S	I					
BORING NO. <u>E.T. #1</u>	T	W	Qu	S	Groundwater Elev.:				
Station <u>707+364</u>	H	S		T	First Encounter _____ m				
Offset <u>4.88 m Left</u>		(/150			Upon Completion _____ m				
Ground Surface Elev. <u>30.48</u> m		mm)	(kPa)	(%)	After _____ Hrs. _____ m				
<u>PID = 0.4ppm</u>									
Brown Silty Clay Loam									
<u>PID = 0.4ppm</u>									
29.11									
Brown Silty Clay									
<u>PID = 0.6ppm</u>									
28.50									
Brown Silty Clay Loam									
<u>PID = 0.2ppm</u>									
-3.0									
<u>PID = 0.2ppm</u>									
<u>PID = 0.2ppm</u>									
25.60									
End of Investigation									
Assume elevation 100 ft									
Background = 0.4ppm									
End of Boring									
-6.0									

The Unconfined Compressive Strength (UCS) Failure Mode is indicated by (B-Bulge, S-Shear, P-Penetrometer)
The SPT (N value) is the sum of the last two blow values in each sampling zone (AASHTO T206)

BBS, form 137 (Rev. 8-99)



**Illinois Department
of Transportation**
Division of Highways
Illinois Department of Transportation

SOIL BORING LOG

Page 1 of 1

Date _____

ROUTE FAP 600 DESCRIPTION Environmental Testing (Traffic Signals at IL 159 and Glen Carbon Road) LOGGED BY _____

SECTION 127-1R-3, (34-1)-1 LOCATION NW corner, SEC. , TWP. , RNG. ,
Latitude , Longitude

COUNTY Madison DRILLING METHOD Hand Auger HAMMER TYPE _____

STRUCT. NO. _____	D	B	U	M	Surface Water Elev. _____ m	D	B	U	M
Station _____	E	L	C	O	Stream Bed Elev. _____ m	E	L	C	O
	P	O	S	I		P	O	S	I
BORING NO. <u>E.T. #2</u>	T	W	Qu	S	Groundwater Elev.:	T	W	Qu	S
Station <u>707+390</u>	H	S		T	First Encounter _____ m	H	S		T
Offset <u>7.92 m Left</u>		(/150			Upon Completion _____ m		(/150		
Ground Surface Elev. <u>30.40</u> m		mm)	(kPa)	(%)	After _____ Hrs. _____ m		mm)	(kPa)	(%)
Brown Silty Clay					contamination.				
					End of Boring				
<u>PID = 1.1ppm</u>									
-1.5									
<u>PID = 0.9ppm</u>									
<u>PID = 0.8ppm</u>									
28.65									
Brown Clay									
<u>PID = 0.9ppm</u>									
<u>PID = 0.8ppm</u>									
27.74									
Brown Silty Clay									
-3.0									
<u>PID = 0.7ppm</u>									
26.52									
End of H.A. @ 13 ft									
Assume elevation 100 ft									
Background Reading = 1.0 ppm									
Sampled at 3', 5', 6', 8', 9', and 13'.									
No readings above background level									
No odor or color indicating									
-6.0									

The Unconfined Compressive Strength (UCS) Failure Mode is indicated by (B-Bulge, S-Shear, P-Penetrometer)
The SPT (N value) is the sum of the last two blow values in each sampling zone (AASHTO T206)

BBS, form 137 (Rev. 8-99)

HMG
ENGINEERS

IL PROF DESIGN FIRM 184,000899

USER NAME = nseelhoefer	DESIGNED -	REVISED -
DRAWN -	REVISED -	
PLOT SCALE = 10,0000 ' / in.	CHECKED -	REVISED -
PLOT DATE = 6/30/2022	DATE -	REVISED -

STATE OF ILLINOIS
DEPARTMENT OF TRANSPORTATION

IL 159 & COTTONWOOD/GLEN CARBON ROAD
SOIL BORINGS

SCALE: SHEET OF SHEETS STA. TO STA.

FAU RTE	SECTION	COUNTY	TOTAL SHEETS	SHEET NO.
8887	(122,122-1,30)RS-4	MADISON	328	285
CONTRACT NO. 76M87				
ILLINOIS FED. AID PROJECT				

Page 1 of 1

Date 4/11/90

COUNTY Madison DRILLING METHOD _____ HAMMER TYPE _____

				Gray and Brown Silty CLAY (continued)	553.80	3 4	0.9 S/10	26
Gray Silty CLAY				END OF BORING End of Boring				
		1						
		1	0.7		25			
		2	S/10					
	-5	1						
		1	0.4		30			
		1	S/10					
	568.30							
Brown and Gray Silty CLAY		1						
		1	0.3	32				
		1	S/10					
	-10	1						
		2	0.7	28				
		2	S					
		1						
		3	0.7	29				
		6	S/15					
	560.80							
Gray and Brown Silty CLAY	-15	1						
		4	1.3	28				
		4	S/10					
		1						
		2	0.6	26				
		4	S/15					
	-20	1						

BBS, form 137 (Rev. 8-99)

Page 1 of 1

Date 4/11/90

COUNTY Madison DRILLING METHOD _____ HAMMER TYPE _____

Brown Silty CLAY				Reddish Brown Silty Sandy Gravelly CLAY (<i>continued</i>)	554.60	2	0.6 S/10	22
				END OF BORING End of Boring				
	1							
	2	0.7	27					
	2	S						
	1							
-5	1	1.0	27					
	2	S						
	1							
	2	0.9	28					
	3	S						
	1							
-10	2	0.8	27					
	3	S/10						
	1							
	3	1.0	29					
	4	S/15						
	1							
-15	3	1.2	27					
	3	S/15						
	1							
	2	1.0	26					
	3	S/10						
556.10	1							
-20								

BBS, form 137 (Rev. 8-99)

Page 1 of 1

Date 4/11/90

COUNTY Madison DRILLING METHOD _____ HAMMER TYPE _____

DEPTH	BLOW COUNTS	UCS	MOISTURE
(ft)	(/6")	(tsf)	(%)

T H (ft)	W S (1/6")	Qu (tsf)	S T (%)
----------------	------------------	-------------	---------------

The Unconfined Compressive Strength (UCS) Failure Mode is indicated by (B-Bulge, S-Shear, P-Penetrometer)
The SPT (N value) is the sum of the last two blow values in each sampling zone (AASHTO T206)

Page 1 of 1

Date 4/16/90

COUNTY Madison DRILLING METHOD _____ HAMMER TYPE _____

D E P T H	B L O W S	U C S Qu	M O I S T
(ft)	((/6"))	(tsf)	(%)

T H	W S	Qu	S T
(ft)	(/6")	(tsf)	(%)

The Unconfined Compressive Strength (UCS) Failure Mode is indicated by (B-Bulge, S-Shear, P-Penetrometer)
The SPT (N value) is the sum of the last two blow values in each sampling zone (AASHTO T206)

USER NAME = nseelhoefer	DESIGNED -	REVISED -
	DRAWN -	REVISED -
PLOT SCALE = 10,0000 ' / in.	CHECKED -	REVISED -
PLOT DATE = 6/30/2022	DATE -	REVISED -

**STATE OF ILLINOIS
DEPARTMENT OF TRANSPORTATION**

IL 159 & COTTONWOOD/GLEN CARBON ROAD SOIL BORINGS

SCALE:	SHEET	OF	SHEETS	STA.	TO STA.
--------	-------	----	--------	------	---------

FAU RTE	SECTION	COUNTY	TOTAL SHEETS	SHEET NO.
8887	(122,122-1,30)RS-4	MADISON	328	287
		CONTRACT NO. 76M87		
ILLINOIS		FED. AID PROJECT		



**Illinois Department
of Transportation**
Division of Highways
Illinois Department of Transportation

SOIL BORING LOG

Page 1 of 1

Date 7/17/01

ROUTE FAP 600 DESCRIPTION Traffic Signals at IL 159 and Junction Drive
(Cottonwood Mall Entrance) LOGGED BY Larry Ford

SECTION 127-1R-3, (34-1)-1 LOCATION SE 1/4, SEC. 23, TWP. 4N, RNG. 8W, 3rd PM.
Latitude , Longitude

COUNTY Madison DRILLING METHOD Hollow Stem Auger HAMMER TYPE Automatic 140#

STRUCT. NO. Station	D E P T H	B L O W S	U C S Qu	M O I S T	Surface Water Elev. _____ m Stream Bed Elev. _____ m	D E P T H	B L O W S	U C S Qu	M O I S T
BORING NO. <u>#3 S Quad</u> Station <u>707+676.5</u> Offset <u>20.50 m Right</u> Ground Surface Elev. <u>176.85</u> m	(m)	(/150 mm)	(kPa)	(%)	Groundwater Elev.: First Encounter _____ m Upon Completion <u>172.4</u> m After _____ Hrs. _____ m	(m)	(/150 mm)	(kPa)	(%)
ASPHALT and ROCK	176.70				Gray SILTY CLAY LOAM (continued)	0	2	172 B	29
Brown SILTY LOAM (fill in parking lot)		5	96 S/5	21	End of Boring End of Boring				
	-1.5	5				-7.5			
Gray SILTY CLAY	175.17	3	201 S/5	22					
		5	192 S/10						
		3	163 S/15	26					
Gray and Brown SILTY CLAY LOAM	174.26	3							
	-3.0	2	86 S/15	29		-9.0			
		3							
		1 5	144 S/15	27					
	▽ -4.5	2				-10.5			
		2	96 S/20	31					
Gray SILTY CLAY LOAM	171.82	2							
		2 3	115 S/15	32					
	-6.0					-12.0			

The Unconfined Compressive Strength (UCS) Failure Mode is indicated by (B-Bulge, S-Shear, P-Penetrometer)
The SPT (N value) is the sum of the last two blow values in each sampling zone (AASHTO T206)

BBS, form 137 (Rev. 8-99)



**Illinois Department
of Transportation**
Division of Highways
Illinois Department of Transportation

SOIL BORING LOG

Page 1 of 1

Date 7/17/01

ROUTE FAP 600 DESCRIPTION Traffic Signals at IL 159 and Junction Drive
(Cottonwood Mall Entrance) LOGGED BY Mark Denton

SECTION 127-1R-3, (34-1)-1 LOCATION SE 1/4, SEC. 23, TWP. 4N, RNG. 8W, 3rd PM.
Latitude , Longitude

COUNTY Madison DRILLING METHOD Hollow Stem Auger HAMMER TYPE Automatic 140#

STRUCT. NO. Station	D E P T H	B L O W S	U C S Qu	M O I S T	Surface Water Elev. _____ m Stream Bed Elev. _____ m	D E P T H	B L O W S	U C S Qu	M O I S T
BORING NO. <u>#4 N Quad</u> Station <u>707+702.6</u> Offset <u>20.50 m Left</u> Ground Surface Elev. <u>178.34</u> m	(m)	(/150 mm)	(kPa)	(%)	Groundwater Elev.: First Encounter _____ m Upon Completion <u>Dry Hole</u> m After _____ Hrs. _____ m	(m)	(/150 mm)	(kPa)	(%)
Brown and Gray SILTY CLAY LOAM		5							
		6 7							
	-1.5	5							
		6 7	105 S/15	26					
		1							
		3 2	48 S/15	29					
	-3.0	3							
	175.14	4 5	220 S/15	25					
Gray and Brown SILTY LOAM		2							
		3 4	125 S/10	27					
	173.92	2							
Brown SILTY CLAY LOAM	173.46	3 3	105 B	26					
End of Boring End of Boring									
	-6.0								

The Unconfined Compressive Strength (UCS) Failure Mode is indicated by (B-Bulge, S-Shear, P-Penetrometer)
The SPT (N value) is the sum of the last two blow values in each sampling zone (AASHTO T206)

BBS, form 137 (Rev. 8-99)

MODEL Default
FILE NAME: I:\03066\DOT-Div8-RTB\194_059\066_0.10_WC1_IL159\CAD_Sheets\0876M87-shl-BoringSheets.dgn

HMG
ENGINEERS

IL PROF DESIGN FIRM 184,000899

USER NAME = nseelhofer	DESIGNED -	REVISED -
DRAWN -	REVISED -	
PLOT SCALE = 10,000' / in.	CHECKED -	REVISED -
PLOT DATE = 6/30/2022	DATE -	REVISED -

STATE OF ILLINOIS
DEPARTMENT OF TRANSPORTATION

IL 159 & JUNCTION DRIVE
SOIL BORINGS

SCALE: SHEET OF SHEETS STA. TO STA.

FAU RTE	SECTION	COUNTY	TOTAL SHEETS	SHEET NO.
8887	(122,122-1,30)RS-4	MADISON	328	288
CONTRACT NO. 76M87				
ILLINOIS FED. AID PROJECT				



**Illinois Department
of Transportation**
Division of Highways
Illinois Department of Transportation

SOIL BORING LOG

Page 1 of 1

Date 10/27/86

ROUTE FAP 600 DESCRIPTION Traffic Signals at IL 159 and Junction Drive
(Cottonwood Mall Entrance) LOGGED BY J. King

SECTION 127-1R-3, (34-1)-1 LOCATION SE 1/4, SEC. 23, TWP. 4N, RNG. 8W, 3rd PM.
Latitude , Longitude

COUNTY Madison DRILLING METHOD Hand Auger HAMMER TYPE

STRUCT. NO. _____ Station _____	D E P T H	B L O W S	U C S Qu	M O I S T	Surface Water Elev. _____ m Stream Bed Elev. _____ m	D E P T H	B L O W S	U C S Qu	M O I S T
BORING NO. 1 East Quad Station 707+705.7 Offset 9.75 m Right Ground Surface Elev. 176.24 m	(m)	(/150 mm)	(kPa)	(%)	Groundwater Elev.: First Encounter _____ m Upon Completion 175.5 m After _____ Hrs. _____ m	(m)	(/150 mm)	(kPa)	(%)
Brown and Gray SILT					Penetrometer End of Boring				
175.47			48	25					
Brown and Gray SILTY CLAY									
175.02			144	25					
Brown and Gray SILTY CLAY TILL									
-1.5			144	34					
			96	33					
-3.0			96	31					
			96	31					
-4.5			96	31					
171.36									
End of Hand Auger									
Due to inaccessability or buried utilities, hand augers were used.									
Qu values obtained from Pocket									
-6.0									

The Unconfined Compressive Strength (UCS) Failure Mode is indicated by (B-Bulge, S-Shear, P-Penetrometer)
The SPT (N value) is the sum of the last two blow values in each sampling zone (AASHTO T206)

BBS, form 137 (Rev. 8-99)



**Illinois Department
of Transportation**
Division of Highways
Illinois Department of Transportation

SOIL BORING LOG

Page 1 of 1

Date 10/27/86

ROUTE FAP 600 DESCRIPTION Traffic Signals at IL 159 and Junction Drive
(Cottonwood Mall Entrance) LOGGED BY J. King

SECTION 127-1R-3, (34-1)-1 LOCATION SE 1/4, SEC. 23, TWP. 4N, RNG. 8W, 3rd PM.
Latitude , Longitude

COUNTY Madison DRILLING METHOD Hand Auger HAMMER TYPE

STRUCT. NO. _____ Station _____	D E P T H	B L O W S	U C S Qu	M O I S T	Surface Water Elev. _____ m Stream Bed Elev. _____ m	D E P T H	B L O W S	U C S Qu	M O I S T
BORING NO. 2 West Quad Station 707+674 Offset 13.72 m Left Ground Surface Elev. 176.30 m	(m)	(/150 mm)	(kPa)	(%)	Groundwater Elev.: First Encounter _____ m Upon Completion 175.5 m After _____ Hrs. _____ m	(m)	(/150 mm)	(kPa)	(%)
Brown and Gray SILT					Penetrometer End of Boring				
175.38			48	32					
Brown and Gray SILTY CLAY									
-1.5			192	34					
174.47									
Brown and Gray SILTY CLAY TILL									
			144	33					
-3.0			96	31					
			96	31					
-4.5			96	31					
171.42									
End of Hand Auger									
Due to inaccessability or buried utilities, hand augers were used.									
Qu values obtained from Pocket									
-6.0									

The Unconfined Compressive Strength (UCS) Failure Mode is indicated by (B-Bulge, S-Shear, P-Penetrometer)
The SPT (N value) is the sum of the last two blow values in each sampling zone (AASHTO T206)

BBS, form 137 (Rev. 8-99)

MODEL Default
FILE NAME: 103066_10DOT_Dkt8_PTB184_059066_010_WC11_IL159CAD_Sheets10876M87-eh-BoringSheets.dgn

HMG
ENGINEERS

IL PROF DESIGN FIRM 184,000899

USER NAME = nseelhoefer

DESIGNED -

REVISED -

DRAWN -

REVISED -

PLOT SCALE = 10,000 ' / in.

CHECKED -

REVISED -

PLOT DATE = 6/30/2022

DATE -

REVISED -

STATE OF ILLINOIS
DEPARTMENT OF TRANSPORTATION

IL 159 & JUNCTION DRIVE
SOIL BORINGS

SCALE:

SHEET

OF

SHEETS

STA.

TO STA.

FAU
RTE

SECTION

COUNTY

TOTAL
SHEETS

SHEET
NO.

8887

(122,122-1,30)RS-4

MADISON

328

289

CONTRACT NO. 76M87

ILLINOIS FED. AID PROJECT

Page 1 of 1

Date 3/23/93

COUNTY Madison DRILLING METHOD Hand Auger HAMMER TYPE DCP

END OF HAND AUGER			
Pocket Penetrometer used for Qu	-15		
Due to inaccessability or buried utilities, Hand Augers were used. "N" values shown are calibrated from a curve converting Dynamic Cone N to SPT "N".			
Reference ASTM STP 399			
End of Boring			
	-20		

BBS, form 137 (Rev. 8-99)

Page 1 of 1

Date 3/23/93

COUNTY Madison DRILLING METHOD Hand Auger HAMMER TYPE DCP

END OF HAND AUGER			
Pocket Penetrometer used for	-15		
Qu			
Due to inaccessability or buried			
utilities, Hand Augers were used.			
"N" values shown are calibrated			
from a curve converting Dynamic			
Conre N to SPT "N".			
Reference ASTM STP 399			
End of Boring			
	-20		

BBS, form 137 (Rev. 8-99)



Page 1 of 1

Date 9/30/08

ROUTE	FAP 600	DESCRIPTION	Traffic Signals at IL 159 & Main Street	LOGGED BY S. Wiszkon
--------------	---------	--------------------	---	-----------------------------

SECTION 60-(30,31,128)-1 LOCATION SEC. 34, TWP. 3N, RNG. 8W, 3rd PM,
Latitude , Longitude

COUNTY Madison / St. Clair DRILLING METHOD Hand Auger HAMMER TYPE _____

STRUCT. NO.	N/A	D	B	U	M	Surface Water Elev.	_____	ft
Station	N/A	E	L	C	O	Stream Bed Elev.	_____	ft
BORING NO.	TS 11 SW Quad	P	O	S	I	Groundwater Elev.:		
Station	157+41	H	S	Qu	T	First Encounter	553.0	ft▼
Offset	32.0 ft LT					Upon Completion	_____	ft
Ground Surface Elev.	565.00	ft	(ft)	(/6")	(taf)	After Hrs.	_____	ft
					(%)			

Asphalt & Concrete	564.00		--	--
			1.2	33
Brown Silty Clay LOAM			1.5	29
			1.5	28
			0.8	27
	-5		0.5	20
			0.8	27
			0.6	28
			0.8	28
			0.8	27
	-10		1.0	29
			1.1	30
	553.00		1.1	--
Gray/Brown Silty Clay LOAM	552.00			
END OF HAND AUGER				
End of Boring				
	-15			
	-20			

The Unconfined Compressive Strength (UCS) Failure Mode is indicated by (B-Bulge, S-Shear, P-Penetrometer)
The SPT (N value) is the sum of the last two blow values in each sampling zone (AASHTO T206)



Page 1 of 1

Date 3/23/93

ROUTE	FAP 600	DESCRIPTION	Traffic Signals at IL 159 & Main Street	LOGGED BY	L. Ford
--------------	---------	--------------------	---	------------------	---------

SECTION 60-(30,31,128)-1 LOCATION SEC. 34, TWP. 3N, RNG. 8W, 3rd PM,
Latitude Longitude

COUNTY Madison / St. Clair DRILLING METHOD Hand Auger HAMMER TYPE DCP

STRUCT. NO. _____	N/A	D	B	U	M	Surface Water Elev. _____	ft
Station _____	N/A	E	L	C	O	Stream Bed Elev. _____	ft
		P	L	S	I		
BORING NO. _____	TS 12 SE Quad	T	W	Q	T	Groundwater Elev.: _____	
Station _____	157+76	H	S	Qu		First Encounter _____	Dry Hole ft
Offset _____	22.0 ft RT					Upon Completion _____	ft
Ground Surface Elev. _____	500.00	ft	(ft)	(/6")	(tsf)	(%)	After _____ Hrs. _____

[illegible]

The Unconfined Compressive Strength (UCS) Failure Mode is indicated by (B-Bulge, S-Shear, P-Penetrometer)
The SPT (N value) is the sum of the last two blow values in each sampling zone (AASHTO T206)



Page 1 of 1

Date 9/30/08

ROUTE	FAP 600	DESCRIPTION	Traffic Signals at IL 159 & Main Street	LOGGED BY S. Wiszkon
--------------	---------	--------------------	---	-----------------------------

SECTION 60-(30,31,128)-1 LOCATION SEC. 34, TWP. 3N, RNG. 8W, 3rd PM,
Latitude Longitude

COUNTY	Madison / St. Clair	DRILLING METHOD	Hand Auger	HAMMER TYPE
---------------	---------------------	------------------------	------------	--------------------

STRUCT. NO.	N/A	D	B	U	M	Surface Water Elev.	_____	ft
Station	N/A	E	L	C	O	Stream Bed Elev.	_____	ft
		P	O	S	I			
BORING NO.	TS 13 NW Quad	T	W			Groundwater Elev.:		
Station	158+92	H	S	Qu	S	First Encounter	Dry Hole	ft
Offset	46.0 ft LT					Upon Completion		ft
Ground Surface Elev.	563.80	ft	(ft)	(/6")	(tsf)	After	Hrs.	ft

[illegible]

The Unconfined Compressive Strength (UCS) Failure Mode is indicated by (B-Bulge, S-Shear, P-Penetrometer)
The SPT (N value) is the sum of the last two blow values in each sampling zone (AASHTO T206)



Page 1 of 1

Date 9/30/08

ROUTE	FAP 600	DESCRIPTION	Traffic Signals at IL 159 & Main Street	LOGGED BY S. Wiszkor
--------------	---------	--------------------	---	-----------------------------

SECTION 60-(30,31,128)-1 LOCATION SEC. 34, TWP. 3N, RNG. 8W, 3rd PM,
Latitude Longitude

COUNTY	Madison / St. Clair	DRILLING METHOD	Hand Auger	HAMMER TYPE
---------------	---------------------	------------------------	------------	--------------------

STRUCT. NO. _____	N/A	D E P T H	B L O W S	U C S	M O I S T	Surface Water Elev. _____	ft	
Station _____	N/A					Stream Bed Elev. _____	ft	
BORING NO. _____	TS 14 NE Quad	H S	Qu	T	Qu	Groundwater Elev.: _____		
Station _____	158+39					First Encounter _____	Dry Hole	ft
Offset _____	61.0 ft RT					Upon Completion _____		ft
Ground Surface Elev. _____	563.80					After _____	Hrs.	ft
		ft	(ft)	(/6")	(tsf)	(%)		

[illegible]

The Unconfined Compressive Strength (UCS) Failure Mode is indicated by (B-Bulge, S-Shear, P-Penetrometer)
The SPT (N value) is the sum of the last two blow values in each sampling zone (AASHTO T206)



SOIL BORING LOG

Page 1 of 1

Date 3/13/91

ROUTE FAP 600 DESCRIPTION IL 159 at Vadalabene in Maryville LOGGED BY Larry Ford

SECTION 127-3R-3 LOCATION SW 1/4, SE 1/4, SEC. 2, TWP. 3N, RNG. 8W, 3rd PM,
Latitude , Longitude

COUNTY Madison DRILLING METHOD Hollow Stem Auger HAMMER TYPE 140# Automtic

STRUCT. NO. _____	D	B	U	M	Surface Water Elev. _____	m
Station _____	E	L	C	O	Stream Bed Elev. _____	m
	P	O	S	I		
BORING NO. _____	T	W		S	Groundwater Elev.: _____	
Station _____	H	S	Qu	T	First Encounter _____	175.7 m▼
Offset _____		(/150			Upon Completion _____	m
Ground Surface Elev. _____	m	mm)	(kPa)	(%)	After 1 Hrs. _____	177.7 m▼

Brown and Gray Silty CLAY			
	2		
	3	163	31
	6	S/15	
	3		
	4	144	32
	4	S/15	
Brown and Gray SILT (Partically Saturated)			
	2		
	4	96	27
	5	S	
Gray Clayey SILT			
	2		
	5	96	29
	7	S	
	4		
	4	163	27
	5	S/15	
	2		
End of Boring End of Boring			
	3	96	28
	5	S	

The Unconfined Compressive Strength (UCS) Failure Mode is indicated by (B-Bulge, S-Shear, P-Penetrometer)
The SPT (N value) is the sum of the last two blow values in each sampling zone (AASHTO T206)

BBS, form 137 (Rev. 8-99)



SOIL BORING LOG

Page 1 of 1

Date 3/13/91

ROUTE FAP 600 DESCRIPTION IL 159 at Vadalabene in Maryville LOGGED BY Larry Ford

SECTION	127-3R-3	LOCATION	SW 1/4, SE 1/4, SEC. 2, TWP. 3N, RNG. 8W, 3 rd PM, Latitude , Longitude
---------	----------	----------	---

COUNTY Madison DRILLING METHOD Hand Auger HAMMER TYPE DCP

STRUCT. NO. _____	D	B	U	M	Surface Water Elev. _____ m
Station _____	E	L	C	O	Stream Bed Elev. _____ m
	P	O	S	I	
BORING NO. _____	T	W	Q	S	Groundwater Elev.: _____
Station _____	H	S	Qu	T	First Encounter _____ 177.1 m▼
Offset _____		(150			Upon Completion _____ m
Ground Surface Elev. _____	m	mm)	(kPa)	(%)	After 0 Hrs. _____ 177.5 m▼

Dark Gray Silty CLAY		67	31
	5	115	29
		96	28
177.42			
	7	144	32
Gray and Brown Silty CLAY		96	33
-1.5			
176.72		67	30
	5		
		67	33
Brown and Gray Very Silty CLAY			
		96	28
175.90	7		
		172	30
Gray Clayey SILT			
		354	30
-3.0	8		
		260	31
		163	30
		144	29
174.38			
End of Hand Auger			
-4.5			
Pocket Penetrometer used for Qu			
Due to inaccessability or buried utilities,			
Hand Augers were used. "N"			
values shown are			
calibrated from a curve converting			
Dynamic Cone			
N to SPT "N".			
Reference ASTM STP 399			
End of Boring			
-6.0			

The Unconfined Compressive Strength (UCS) Failure Mode is indicated by (B-Bulge, S-Shear, P-Penetrometer)
The SPT (N value) is the sum of the last two blow values in each sampling zone (AASHTO T206)

BBS, form 137 (Rev. 8-99)

1. THE RESIDENT ENGINEER SHALL VERIFY THE EXISTENCE OF HIGHWAY LIGHTING AND/OR INTELLIGENT TRANSPORTATION SYSTEMS (I.T.S.) UTILITIES WITHIN THE PROJECT LIMITS. IF HIGHWAY LIGHTING AND/OR I.T.S. EXISTS WITHIN THE PROJECT LIMITS, AND IF THESE ITEMS REQUIRE LOCATING, THE CONTRACTOR SHALL BE DIRECTED TO DO SO ACCORDING TO SECTION 803 OF THE STANDARD SPECIFICATIONS. THIS WORK SHALL BE PAID FOR ACCORDING TO ARTICLE 109.04 OF THE STANDARD SPECIFICATIONS.



 EX. HANDHOLE
 EX. TRAFFIC SIGNAL CONTROLLER
 EX. DETECTOR LOOP
 EXISTING CONDUIT
 PROPOSED DETECTOR LOOP

1. DRILL OUT PAVEMENT SEALANT AND CLEAN EXISTING CONDUIT.
2. REMOVE EXISTING DETECTOR LOOP WIRES TO HANDHOLE.
3. INSTALL NEW LOOP-IN WIRES TO EXISTING CONDUIT.
4. SPLICE NEW DETECTOR LOOP WIRES TO EXISTING LOOP LEAD-IN CABLE IN HANDHOLE.
5. FILL HOLE WITH APPROVED SEALER. PREVENT SEALER FROM ENTERING CONDUIT.
6. LOCATE UNDERGROUND CABLE WILL BE PAID FOR SEPARATELY.

SCHEDULE OF QUANTITIES

SCALE: N.T.S.	SHEET 1 OF 32 SHEETS	STA.	TO STA.
---------------	----------------------	------	---------

F.A.P RTE.	SECTION	COUNTY	TOTAL SHEETS	SHEET NO.
600	(122, 122-1, 30) RS-4	MADISON	328	296
		CONTRACT NO. 76M87		
ILLINOIS		FED. AID PROJECT		

DETECTOR LOOP REQUIREMENTS AND CALCULATIONS					
LOOP#	PHASE#	LOOP SIZE (FT. X FT.)	NUMBER OF TURNS	CALCULATED RESISTANCE OHMS (Q)	RESISTANCE OHMS (Q)
1. NB THRU CCO	6	6' X 6'	-	2.20	2.20
2. NB THRU CCO	6	6' X 6'	-	2.14	2.14
3. NB LT CD	1	6' X 50' (Q)	- 3	813	2.22
4. NB THRU CD	6	6' X 50' (Q)	- 3	811	2.17
5. NB THRU CD	6	6' X 50' (Q)	- 3	809	2.12
9. SB THRU CCO	2	6' X 6'	-	358	2.71
10. SB THRU CCO	2	6' X 6'	-	355	2.65
11. SB LT CD	5	6' X 50' (Q)	- 3	828	2.57
12. SB THRU CD	2	6' X 50' (Q)	- 3	826	2.51
13. SB THRU CD	2	6' X 50' (Q)	- 3	823	2.45
16. EB LT CD	3	6' X 50' (Q)	- 3	850	3.27
17. EB THRU CD	3	6' X 50' (Q)	- 3	849	3.33
18. EB RT CD	3	6' X 50' (Q)	- 3	847	3.39

THE ABOVE VALUES ARE CALCULATED OF COMBINED LOOP AND LEAD-IN INDUCTANCE AND RESISTANCE. ACTUAL MEASURED VALUES SHOULD BE WITHIN +/- 20% OF THESE VALUES.
Q=QUADRAPOLE

⊕ = SEE DETAIL

NOTES:

SEE TABLE "DETECTOR LOOP REQUIREMENTS AND CALCULATIONS" FOR LOOP SIZE AND CALCULATED NUMBER OF TURNS.
SEE "DETAIL" FOR INSTALLING DETECTOR LOOP WIRES IN EXISTING CONDUITS.

MODEL: \\FUHRMANN\Engineering\Projects\10876487\CAD\Drawings\10876487-16\CADD_Sheets\10876487-16-1\plan1.dgn
FILE: \\FUHRMANN\Engineering\Projects\10876487\CAD\Drawings\10876487-16\CADD_Sheets\10876487-16-1\plan1.dgn



FUHRMANN
ENGINEERING
WWW.FUHRMANN-ENG.COM

USER NAME = Default
PLOT SCALE = 40,0000 * / in.
PLOT DATE = 10/25/2022

DESIGNED - _____
DRAWN - _____
CHECKED - _____
DATE - _____


REVISED - _____
REVISED - _____
REVISED - _____
REVISED - _____

STATE OF ILLINOIS
DEPARTMENT OF TRANSPORTATION

IL ROUTE 159 AND BELTLINE ROAD / PINE LAKE ROAD
DETECTOR LOOP REPLACEMENT PLAN

SCALE: 1"=20' SHEET 2 OF 32 SHEETS STA. _____ TO STA. _____

F.A.P. RTE.	SECTION	COUNTY	TOTAL SHEETS	SHEET NO.
300	(122, 122-1, 30) RS-4	MADISON	328	297
CONTRACT NO. 76M87				
ILLINOIS FED. AID PROJECT				

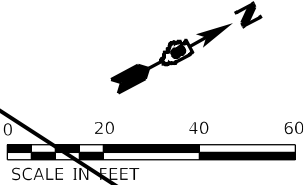


[illegible]

Q=QUADRAPOLE

 = SEE DETAIL

NOTES:

SEE TABLE "DETECTOR LOOP REQUIREMENTS AND CALCULATIONS"
FOR LOOP SIZE AND CALCULATED NUMBER OF TURNS.
SEE "DETAIL" FOR INSTALLING DETECTOR LOOP WIRES
IN EXISTING CONDUITS.

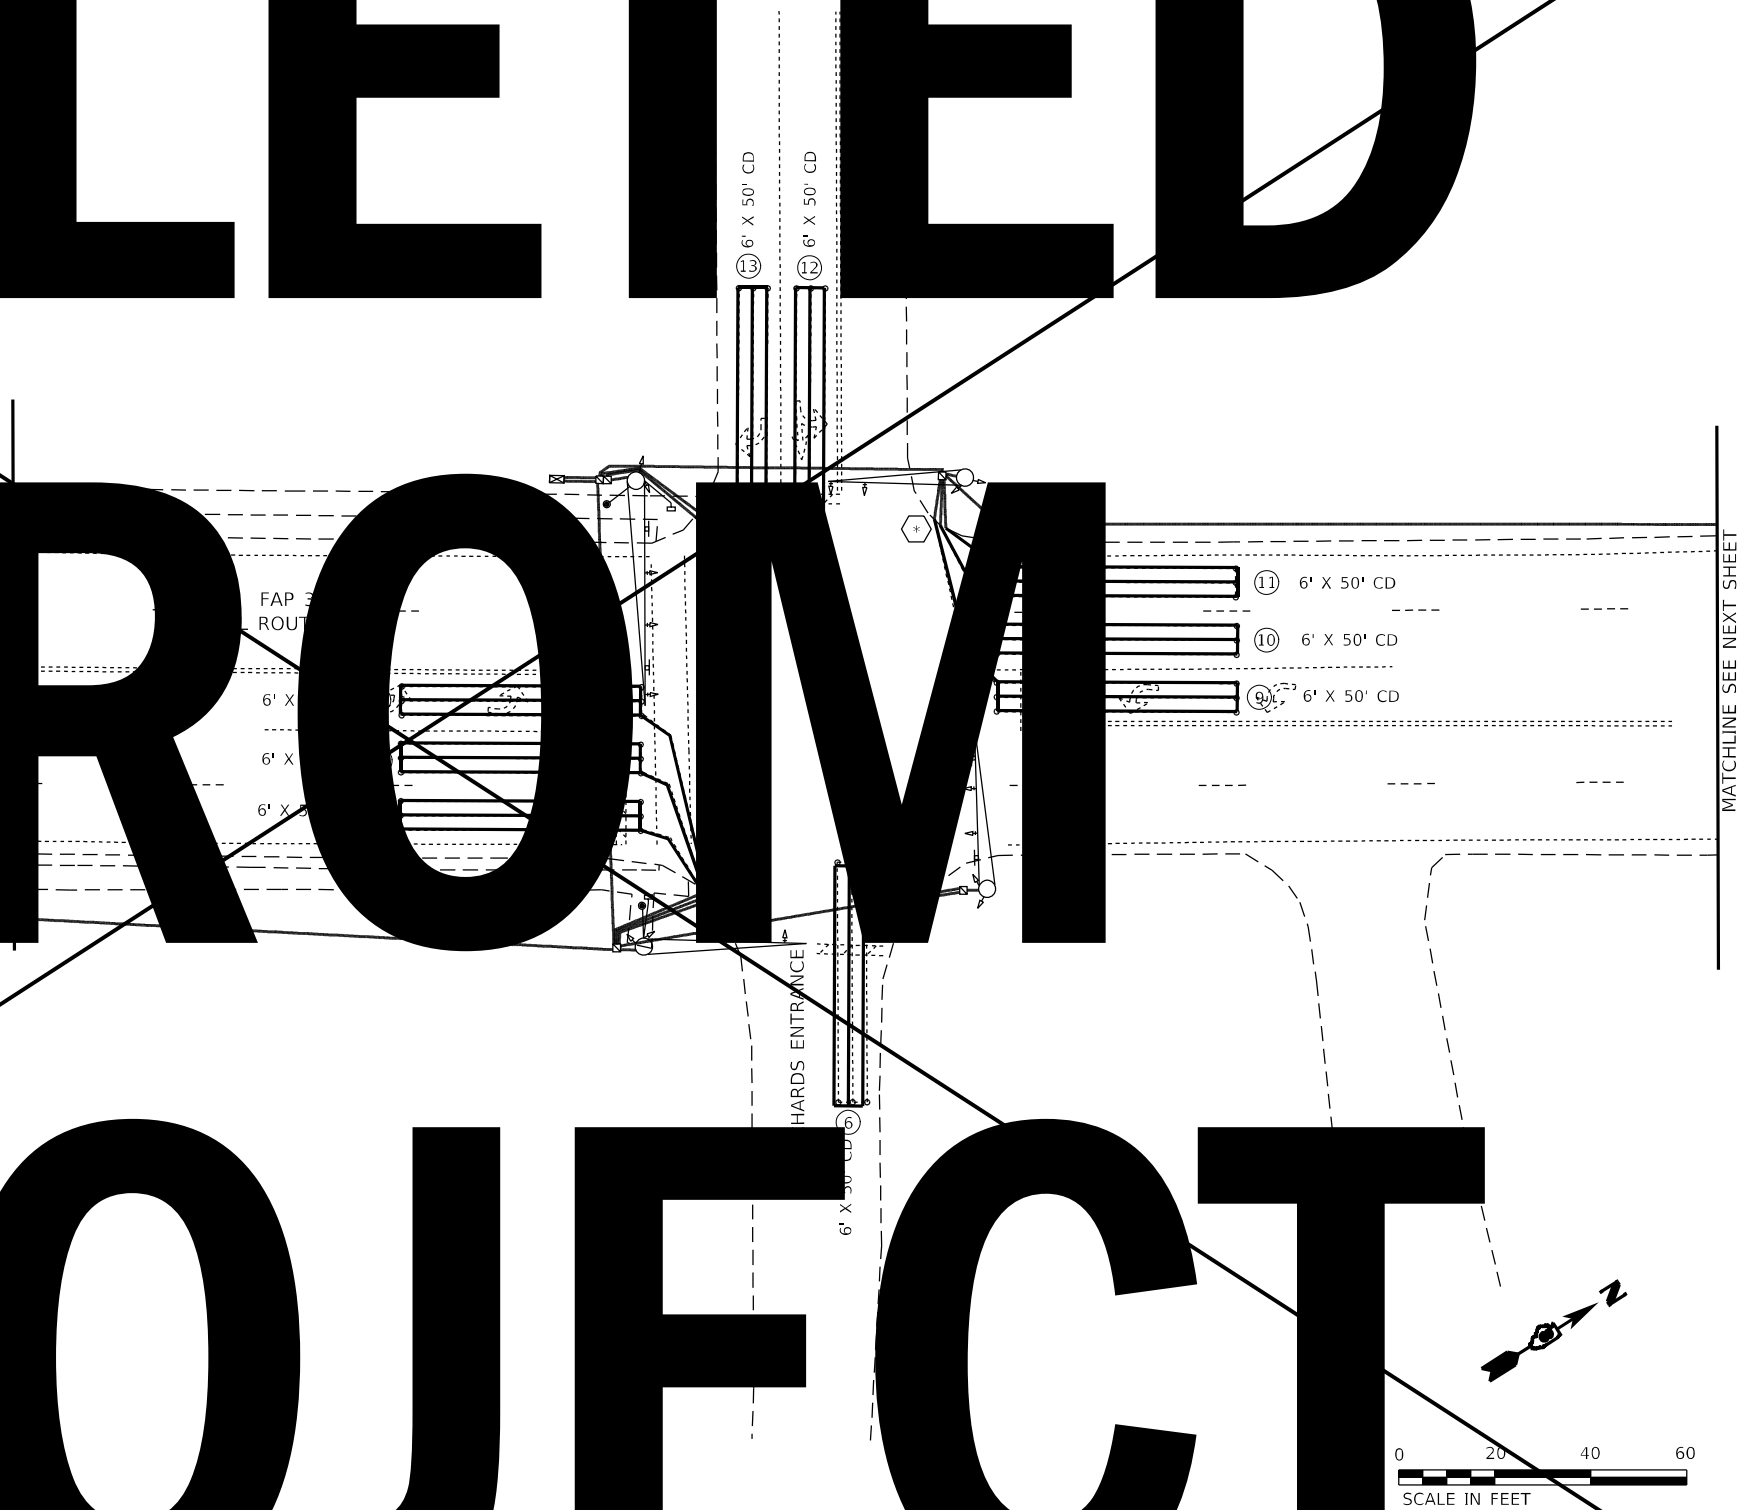

DELETED

FAP 300
(IL ROUTE 159)


6' C

6' X 6' CCO

②

MATCH

FROM

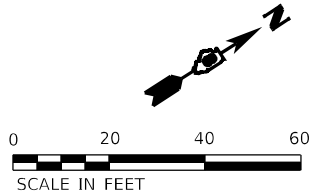

PROJECT

PREVIOUS SHEET

DAN


*

⑧ 6' X 6' CCO

⑦

6' X 6' CCO

FAP 300
(IL ROUTE 159)

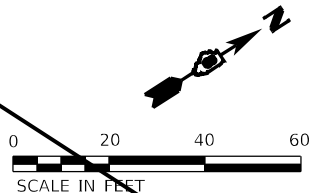

MODEL NAMES
FILE NAME: \\fuhrmann-engineering.com\fuhrmann\DOT Documents\DOT Office\Director_8\Projects\0876487\CADD\Drawings\CADD\Drawings\0876487-Sub-105-021\plan2.dgn