F.A.I RTE.	SECTION	COUNTY	TOTAL SHEETS	SHEET NO.
190	0102.1 S	соок	107	88
FED DO	AD DICT HO THE	ATC CED. ATD. DDG IFGT.		

FED. ROAD DIST. NO. | ILLINOIS | FED. AID PROJECT










 


## NOTES:

- 1. SUPPORT VENDOR CABLES FROM BOTTOM OF INTERMEDIATE LEVEL SLAB AS REQUIRED BY CABLE TRAY. CABLE TRAY ROUTING TO BE COORDINATED WITH HVAC DUCT WORK AND SUPPORTS. SEE DETAIL EGOI.
- 2. SEE DRAWING E34 FOR CONDUCTOR AND CONDUIT REQUIREMENTS.
- 3. CONTRACTOR IS RESPONSIBLE FOR VERIFYING NUMBER OFCONDUCTORS IN CONDUIT PRIOR TO INSTALLATION. LOCATION OFBRANCH CIRCUITS AND SWITCH LEGS AS INDICATED MAY BE ROUTED DIFFERENTLY AS DICTATED BY CONSTRUCTION AND SPECIFICATIONS.
- 4. ALL ROOMS EXCEPT ELECTRICAL ROOM SHALL BE CLASS I, DIVISION I, GROUP D EXPLOSION PROOF.

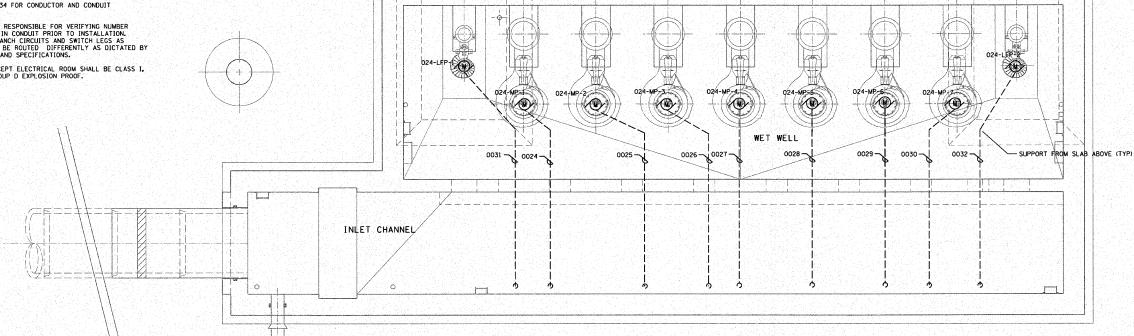

PLAN @ EL. 597.5



ILLINOIS DEPARTMENT OF TRANSPORTATION

PUMP STATION NO. 24 RELOCATION

ELECTRICAL POWER PLAN SHEET 1.

SCALE: AS SHOWN DATE: 11-22-10

E15

REVISIONS NAME

DRAWN BY: MS CHECKED BY: MS

