
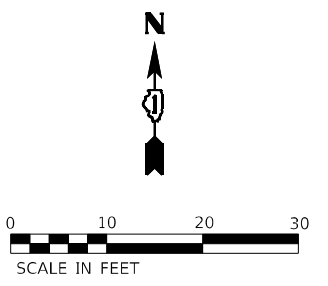


MODEL: Default
FILE: \\state-prod\p\hwy-bentley.com\k-h-pw-d\1\Documents\01 Active Projects\WV-CUS-160950-100 - IL 64\Phase II\2 Design\CAO\Plan Sheets\Roadway\0108121-shr-PMK-21_KHA.dgn

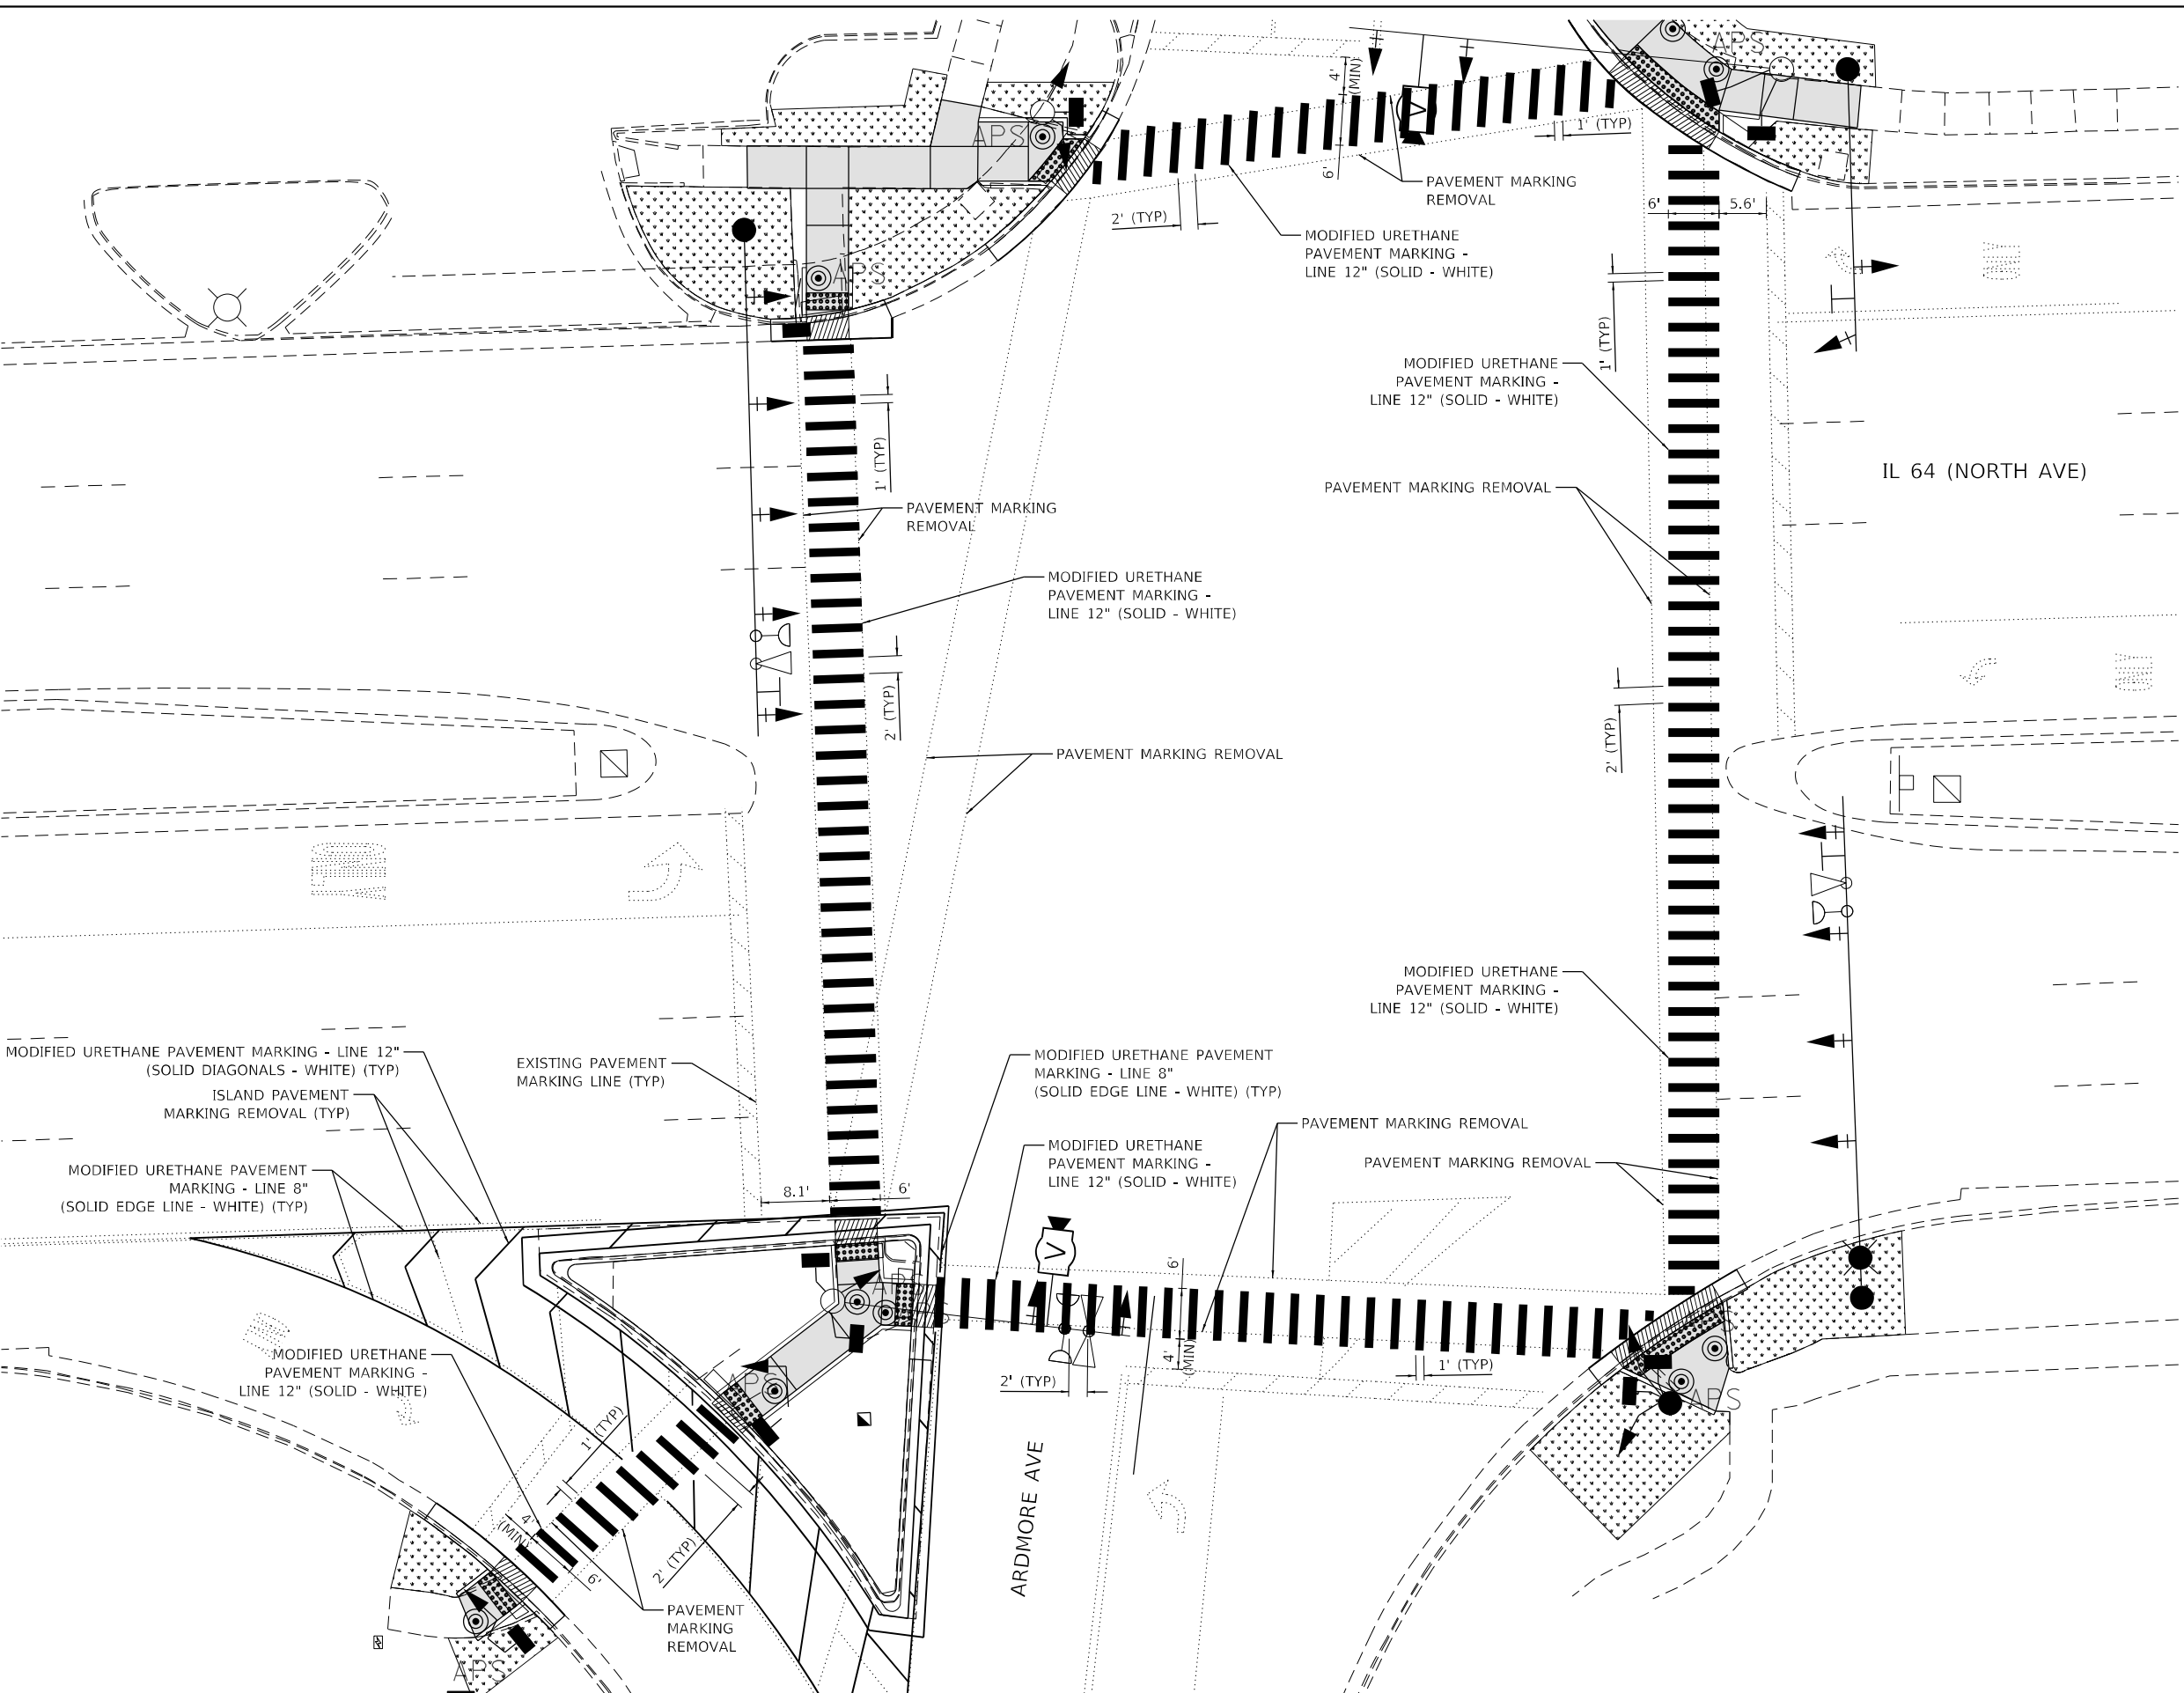

Kimley»Horn

© 2023 KIMLEY-HORN AND ASSOCIATES, INC.
4001 WINFIELD ROAD, SUITE 400
WARREN, IL 6. 60555
PHONE: (847) 465-4655
WWW.KIMLEY-HORN.COM


USER NAME =	DESIGNED -	REVISED -
	DRAWN -	REVISED -
PLOT SCALE =	CHECKED -	REVISED -
PLOT DATE =	DATE -	REVISED -



**STATE OF ILLINOIS
DEPARTMENT OF TRANSPORTATION**

**PAVEMENT MARKING PLAN
IL 64 (NORTH AVE) AND ARDMORE AVE**

SCALE: 1" = 10' SHEET OF SHEETS STA. TO STA.

F.A.P. RTE.	SECTION	COUNTY	TOTAL SHEETS	SHEET NO.
307	2020-263-SUR, SW&TS	DUPAGE	529	102
CONTRACT NO. 62N33				
ILLINOIS FED. AID PROJECT				

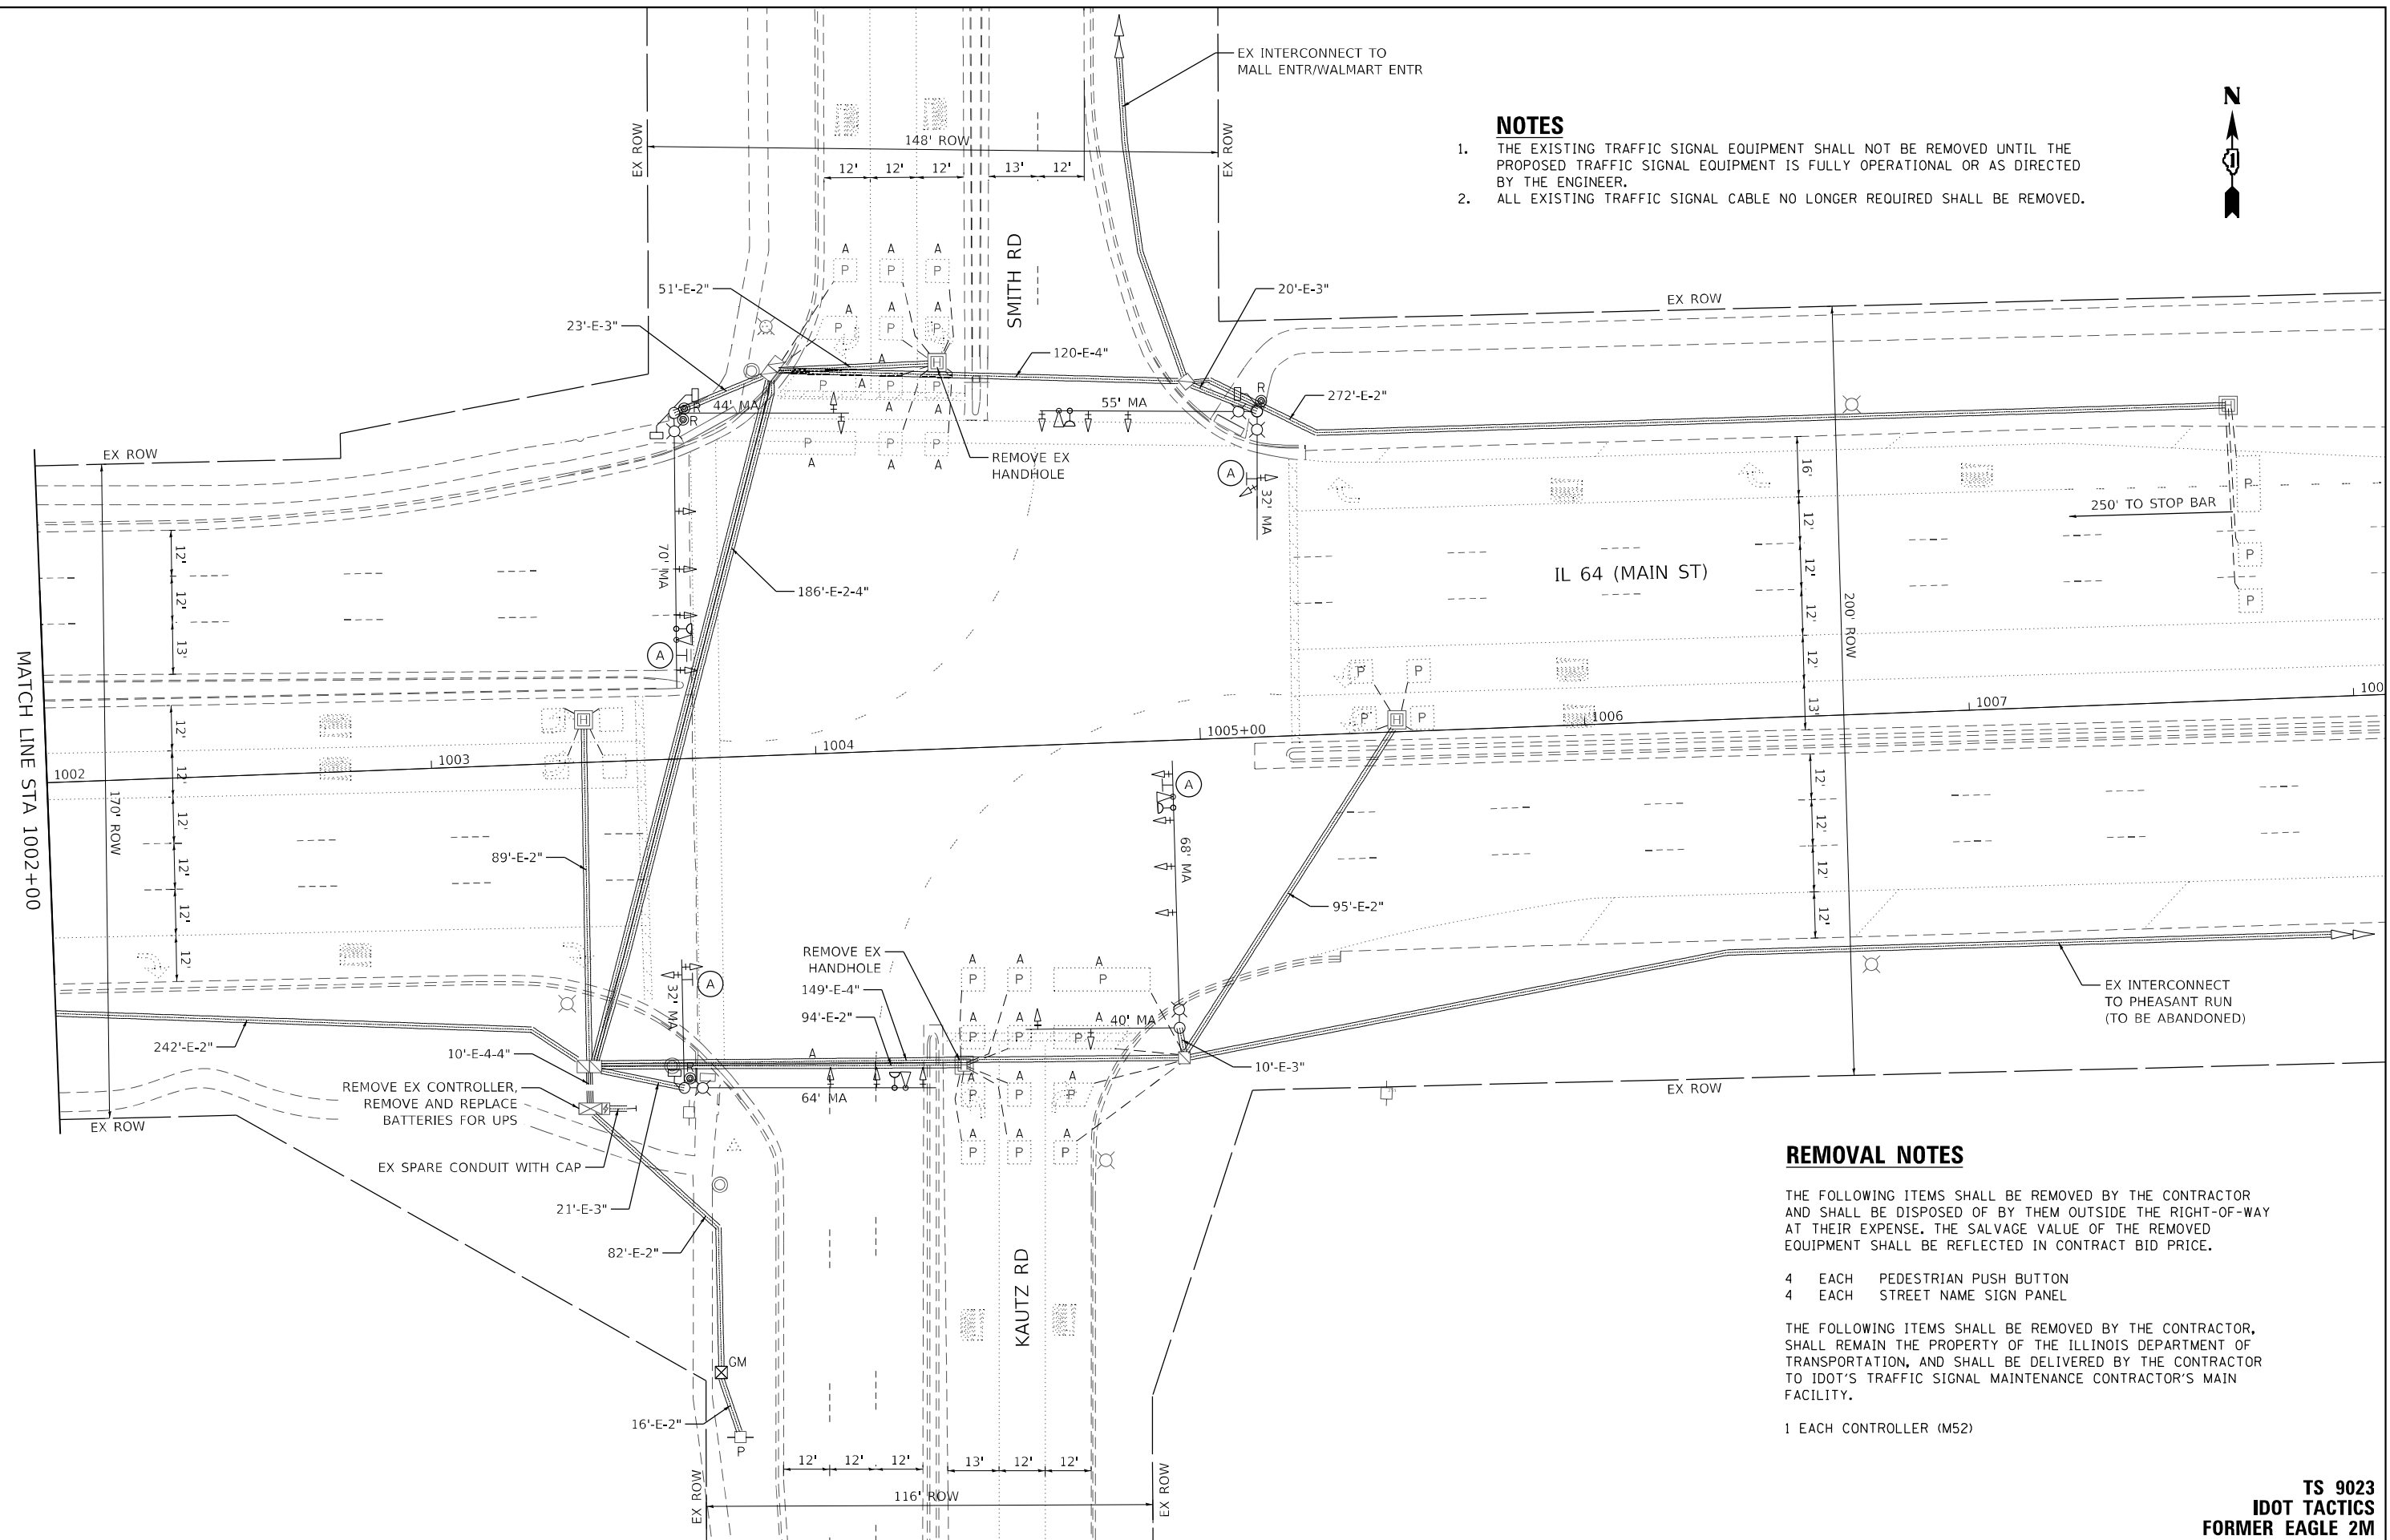

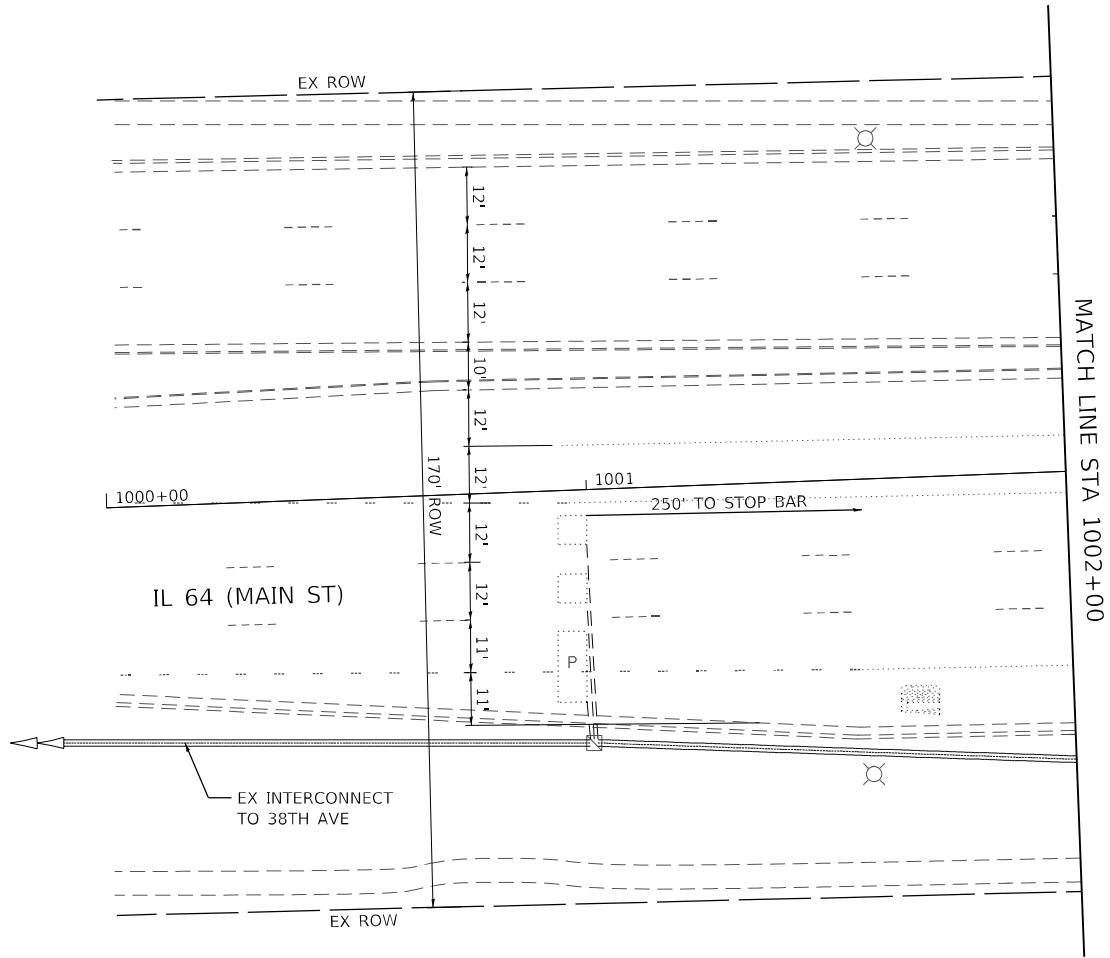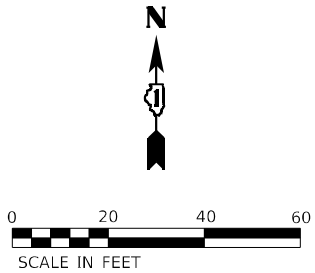

MODEL: Default
FILE: h:\mhc\projects\pva\bartley.com\h-pva-d1\Documents\01 Active Projects\MW\CHS-168950\00 - IL 64\Phase 01\2 Design\CAD\Plan Streets\Signal\West Corridor_Signal\01081714-IL-64-02_KIM.dgn



USER NAME =	DESIGNED -	REVISED -
	DRAWN -	REVISED -
PLOT SCALE =	CHECKED -	REVISED -
PLOT DATE =	DATE -	REVISED -

STATE OF ILLINOIS
DEPARTMENT OF TRANSPORTATION

TRAFFIC SIGNAL EQUIPMENT REMOVAL PLAN
IL 64 (MAIN ST) AND SMITH RD/KAUTZ RD

SCALE: 1" = 20' SHEET OF SHEETS STA. TO STA.

F.A.P. RTE.	SECTION	COUNTY	TOTAL SHEETS	SHEET NO.
307	2020-263-SUR,SW&TS	DUPAGE	529	105
CONTRACT NO. 62N33				
		ILLINOIS	FED. AID PROJECT	

TS 9023
IDOT TACTICS
FORMER EAGLE 2M

A
LEFT ON
GREEN
ARROW
ONLY

R10-5
30" X 36"
(4 REQUIRED)

DRILL EX HANDHOLE (1)

9'-UC-2"

PR 5' PEDESTRIAN POST - 12" DIA. FDN (4' DEPTH)
APPROX. STA. 1003+86, 94 LT

23'-E-3"

APS

44' MA

SMITH RD

55' MA

20'-E-3"

EX 36" DIA. FDN

272'-E-2"

APS

32' MA

IL 64 (MAIN ST)

250' TO STOP BAR

MATCH LINE STA 1002+00

EX ROW

12'

12'

13'

12'

12'

13'

12'

12'

COMMUNICATIONS VAULT
(SEE INTERCONNECT AND
COMMUNICATIONS PLANS)

89'-E-2"

242'-E-2"

EX ROW

PR CONTROLLER, TERMINAL SERVER,
LAYER III SWITCH, FIBER OPTIC
INTERCONNECT CENTER, 48 PORT IN
EX CABINET, REMOVE AND REPLACE
BATTERIES FOR UPS,

10'-E-4-4"

EX SPARE CONDUIT WITH CAP

21'-E-3"

82'-E-2"

32' MA

APS

64' MA

149'-E-4"

40' MA

EX 42" DIA. FDN

10'-E-3"

EX ROW

EX ROW

12'

12'

12'

13'

12'

12'

116' ROW

KAUTZ RD

CCTV-NO-000

68' MA

APS

95'-E-2"

EX ROW

EX ROW

NOTES

1. ALL PROPOSED TRAFFIC SIGNAL CABLE SHALL BE ROUTED THROUGH THE PROPOSED CONDUIT.
2. A SEPARATE LEAD-IN CABLE SHALL BE INSTALLED FOR THE DETECTOR LOOPS ON IL 64 (NORTH AVE).
3. THERE SHALL BE A MINIMUM OF 4' SIDEWALK CLEARANCE IN FRONT/BEHIND OF THE TRAFFIC SIGNAL FOUNDATIONS TO BE ADA COMPLIANT.
4. THE SIDEWALK CURBS ON ALL QUADRANTS SHALL BE CUT SO THAT THE POST AND MAST ARM FOUNDATIONS ARE FLUSH WITH THE EDGE OF THE SIDEWALK.
5. ALL PUSH BUTTONS SHALL BE APS.
6. THIS LOCATION HAS BEEN DESIGNED TO BE ADA COMPLIANT. ANY DEVIATION FROM THIS PLAN FOR THE POSTS THAT HAVE PEDESTRIAN EQUIPMENT WILL HAVE TO BE APPROVED BY THE ENGINEER TO ENSURE ADA COMPLIANCE.
7. CONTRACTOR SHALL VERIFY THAT THE PLACEMENT OF THE PROPOSED SIGNAL EQUIPMENT ADJACENT TO EXISTING RAMPS MEET ADA REQUIREMENTS. THE ENGINEER SHALL APPROVE THE PROPOSED LOCATIONS OF THE SIGNAL EQUIPMENT BEFORE INSTALLATION.

TS 9023
IDOT TACTICS
FORMER EAGLE 2M

KimleyHorn

USER NAME =

DESIGNED -

REVISED -

DRAWN -

REVIS

REVISED -

PLOT SCALE =

CHECKED -

REVISED -

PLOT DATE =

DATE -

REVISED -

STATE OF ILLINOIS
DEPARTMENT OF TRANSPORTATION

TRAFFIC SIGNAL MODERNIZATION PLAN
IL 64 (MAIN ST) AND SMITH RD/KAUTZ RD

SCALE: 1" = 20'

SHEET

OF

SHEETS

STA.

TO STA.

F.A.P.

RTE.

SECTION

COUNTY

TOTAL

SHEETS

SHEET

NO.

307

2020-263-SUR,SW&TS

DUPAGE

529

106

ILLINOIS

FED. AID PROJECT

CONTRACT NO. 62N33

MODEL: Default
FILE NAME: p:\sub-pw\bartley.com\k-h-pw-d1\Documents\01 Active Projects\MW\CL-S-160950\00 - IL 64\Phase II\2 Design\CAD\Plan Sheets\Signal\West Corridor Signal\01081714-IL-64-K4A.dgn



© 2023 KIMLEY-HORN AND ASSOCIATES, INC.
4001 WHITE OAK RD, SUITE 600
WARREN, IL 60555
PHONE: 815.447.4555
WWW.KIMLEY-HORN.COM



USER NAME	=	DESIGNED	-	REVISED	-
		DRAWN	-	REVISED	-
PLOT SCALE	=	CHECKED	-	REVISED	-
PLOT DATE	=	DATE	-	REVISED	-

STATE OF ILLINOIS
DEPARTMENT OF TRANSPORTATION


TRAFFIC SIGNAL MODERNIZATION PLAN IL 64 (MAIN ST) AND SMITH RD/KAUTZ RD			
SCALE: 1" = 20'	SHEET	OF	SHEETS
STA.		TO STA.	

F.A.P. RTE.	SECTION	COUNTY	TOTAL SHEETS	SHEET NO.
307	2020-263-SUR,SW&TS	DUPAGE	529	107
CONTRACT NO. 62N33				
		ILLINOIS	FED. AID PROJECT	


TS 9023
IDOT TACTICS
FORMER EAGLE 2M

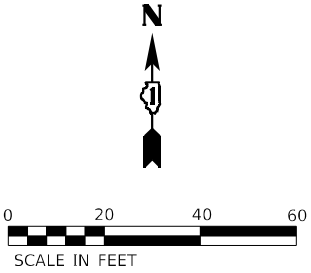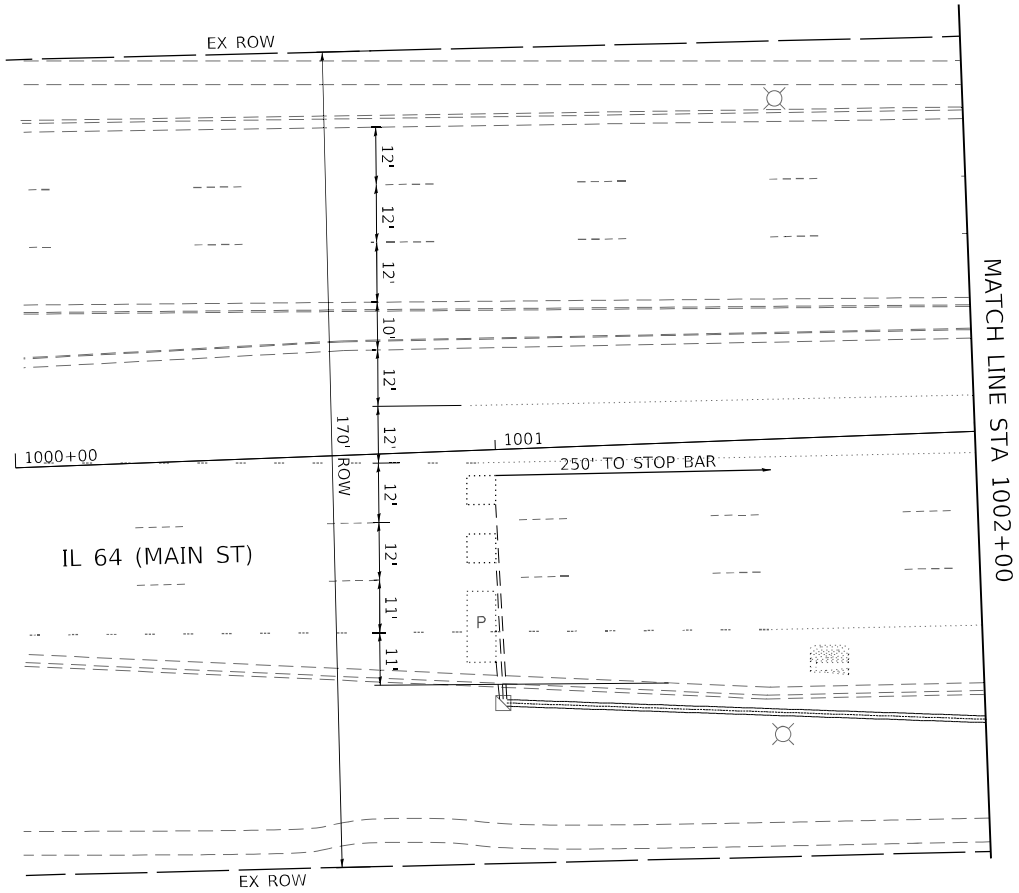

EXISTING AND PROPOSED
CONTROLLER SEQUENCE

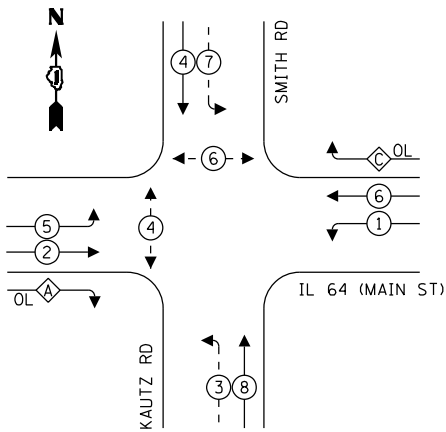


LEGEND:

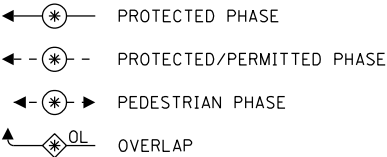

OVERLAP LETTER	PERMISSIVE PHASE	PROTECTED PHASE
A	= 2	+ 3
C	= 6	+ 7

EXISTING AND PROPOSED EMERGENCY
VEHICLE PREEMPTION SEQUENCE

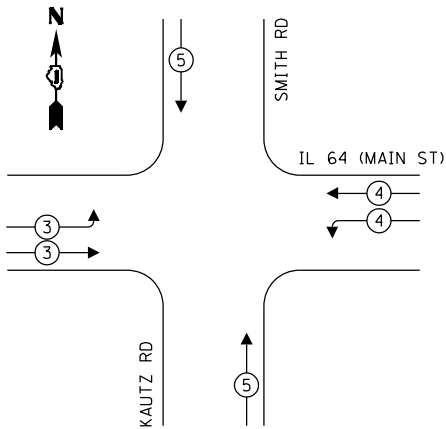

TRAFFIC SIGNAL
ELECTRICAL SERVICE REQUIREMENTS


TYPE	QUANTITY	UNIT WATTAGE	TOTAL WATTAGE
SIGNAL HEAD 1 OR 3-SECTION	14	11	154
4-SECTION	-	14	-
5-SECTION	8	13	104
PROGRAMMABLE 3-SECTION	-	22	-
4-SECTION	-	32	-
5-SECTION	-	28	-
PEDESTRIAN SIGNAL	4	15	60
CONTROLLER	1	150	150
MASTER CONTROLLER	-	100	-
UPS	1	25	25
DETECTION VIDEO	2	20	40
BLANK-OUT SIGN	-	25	-
NETWORK SWITCH LAYER II OR III	1	35	35
CELLULAR MODEM	-	15	-
PTZ	1	75	75
TOTAL UPS SIZING		643	
UPS CHARGING	1	225	225
BATTERY HEATER MAT	1	180	180
CABINET HEATER	1	200	200
FLASHER	-	15	-
LED STREET NAME SIGN	-	120	-
LUMINAIRE	5	240	1200
TOTAL SERVICE WIRE SIZING		2448	

LEGEND:

L = LED LAMP MODULE REPLACEMENT
* = ROADWAY LIGHTING CABLE

ENERGY COSTS TO:
CITY OF ST. CHARLES
2 E MAIN ST
ST. CHARLES, IL 60174

ENERGY SUPPLY: COMPANY: ST. CHARLES ELEC. DEPT.
PHONE: (630) 377-4407
ACCOUNT NUMBER:

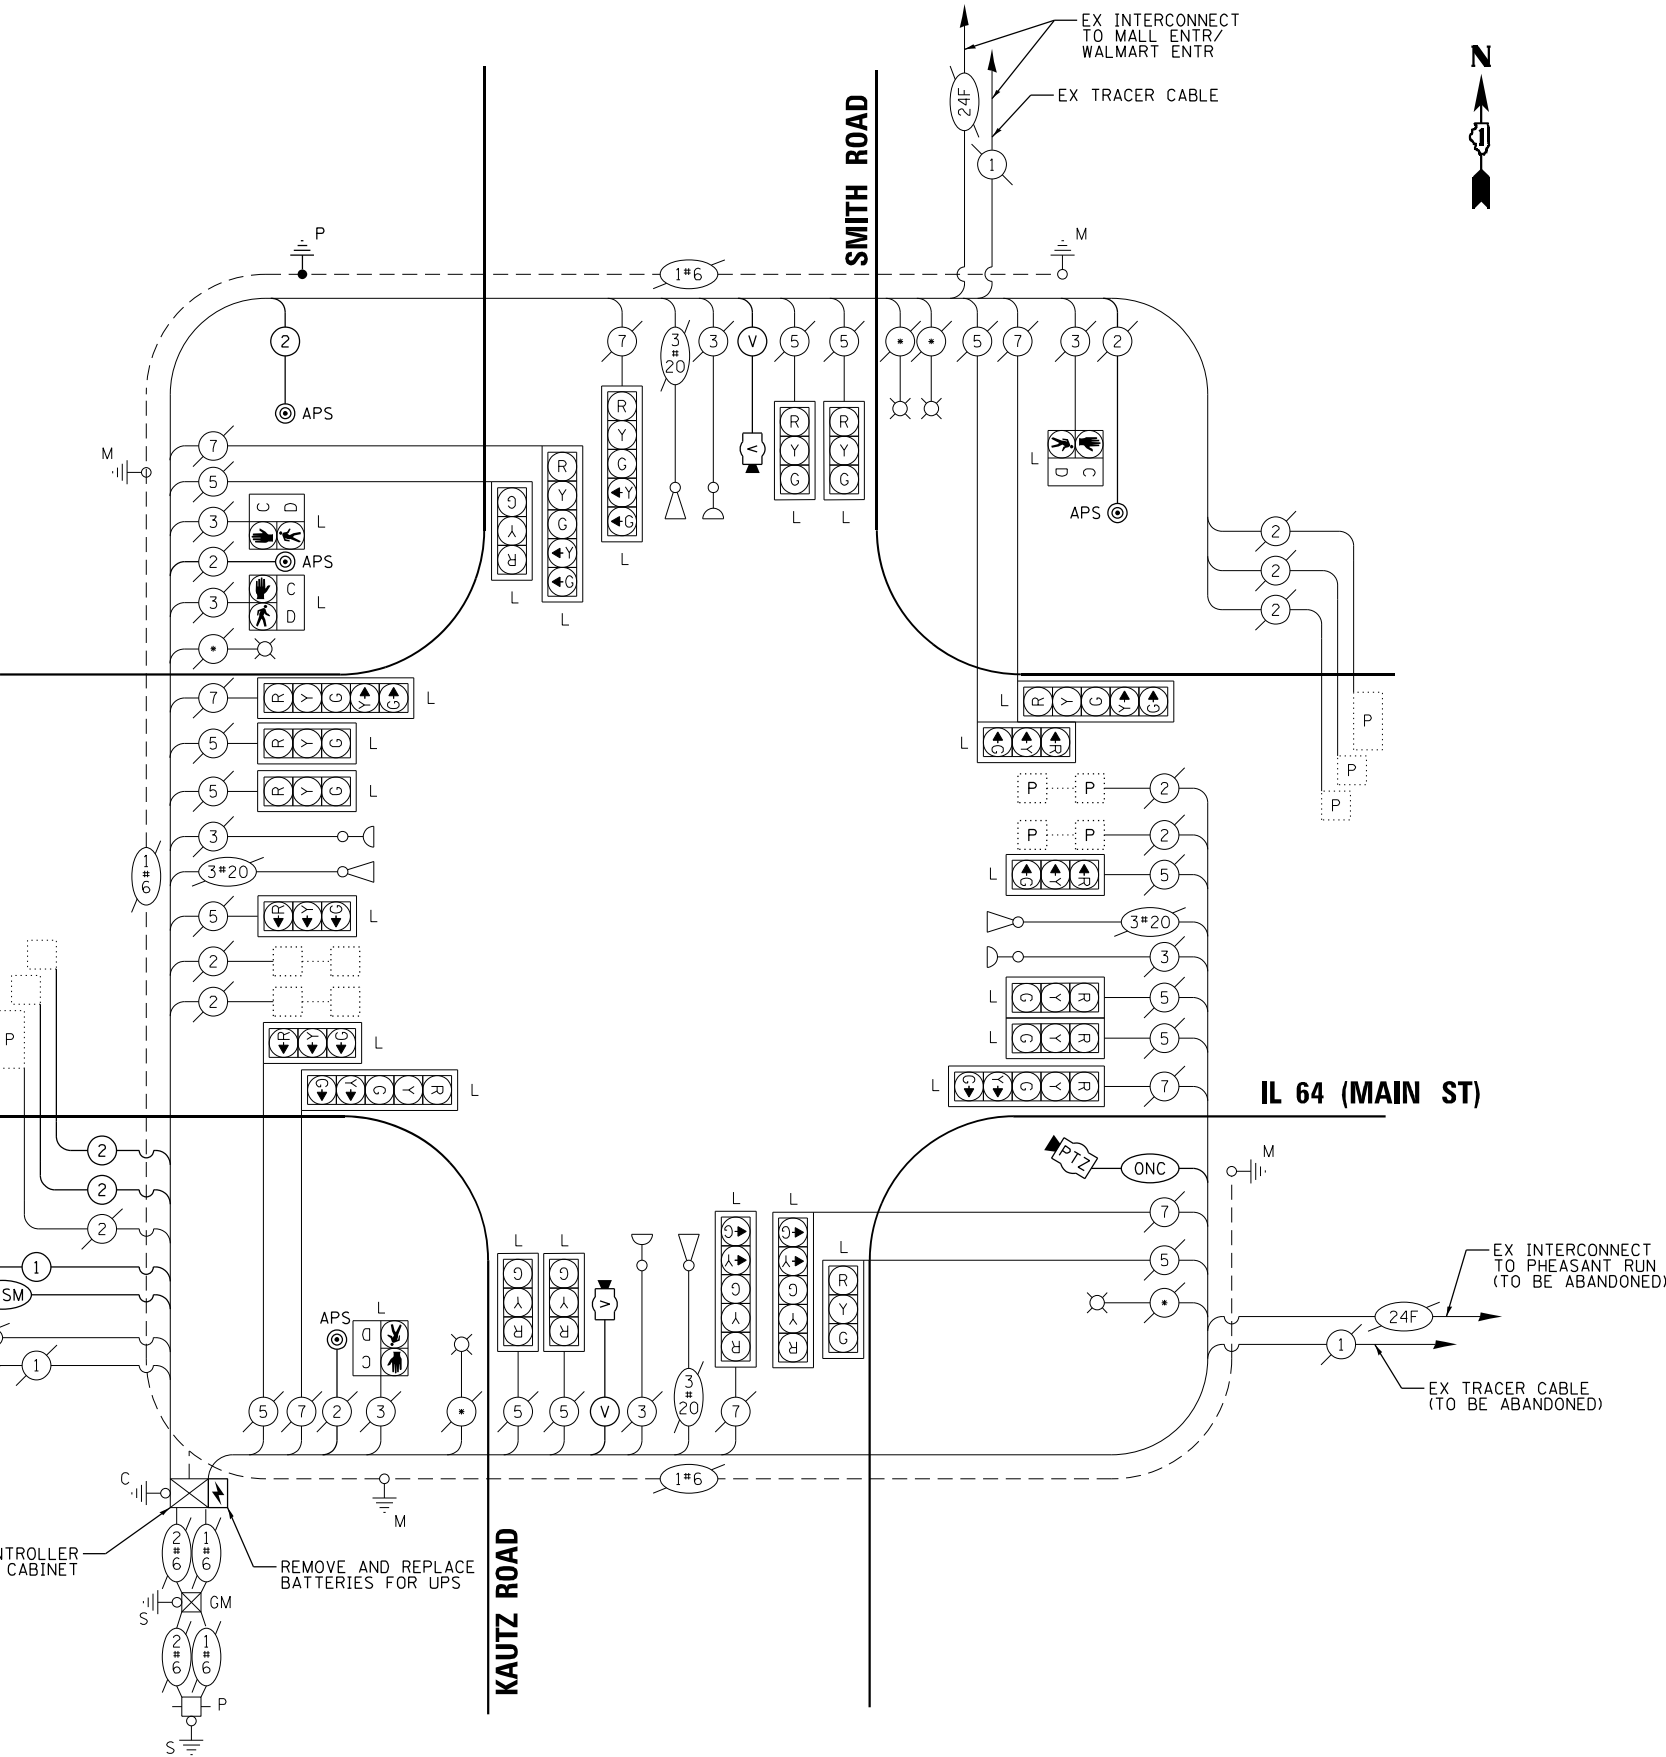

CABLE PLAN
(NOT TO SCALE)

TS 9023
IDOT TACTICS
FORMER EAGLE 2M

KimleyHorn

© 2023 KIMLEY-HORN AND ASSOCIATES, INC.
4001 WILSON D. ROAD, SUITE 600
WARREN, ILL. 60555
PHONE: (847) 458-4555
WWW.KIMLEY-HORN.COM

USER NAME	=	DESIGNED	-	REVISED	-
PLOT SCALE	=	DRAWN	-	REVISED	-
PLOT DATE	=	CHECKED	-	REVISED	-
		DATE	-	REVISED	-

DESIGNED	-	REVISED	-
DRAWN	-	REVISED	-
CHECKED	-	REVISED	-
DATE	-	REVISED	-

STATE OF ILLINOIS
DEPARTMENT OF TRANSPORTATION

CABLE PLAN, PHASE DESIGNATION DIAGRAM, AND
EMERGENCY VEHICLE PREEMPTION SEQUENCE
IL 64 (MAIN ST) AND SMITH RD/KAUTZ RD

SCALE: N.T.S. SHEET OF SHEETS STA. TO STA.


F.A.P. RTE.	SECTION	COUNTY	TOTAL SHEETS	SHEET NO.
307	2020-263-SUR, SW&TS	DUPAGE	529	108
CONTRACT NO. 62N33				
ILLINOIS FED. AID PROJECT				

SIGN PANEL – TYPE 2


ALL DIMENSIONS ARE IN INCHES UNLESS OTHERWISE NOTED



DESIGN SERIES	AREA (SQ FT)	SIGN PANEL TYPE	SHEETING TYPE	QTY. REQUIRED
D	11.25	2	ZZ	2

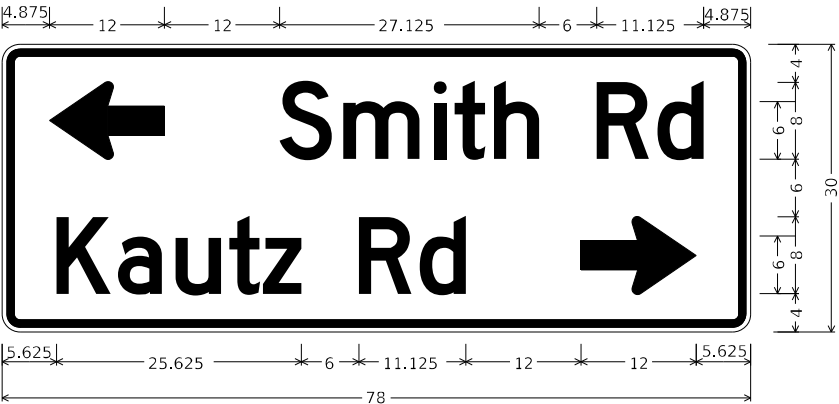

DESIGN SERIES	AREA (SQ FT)	SIGN PANEL TYPE	SHEETING TYPE	QTY. REQUIRED
D	16.25	2	ZZ	2

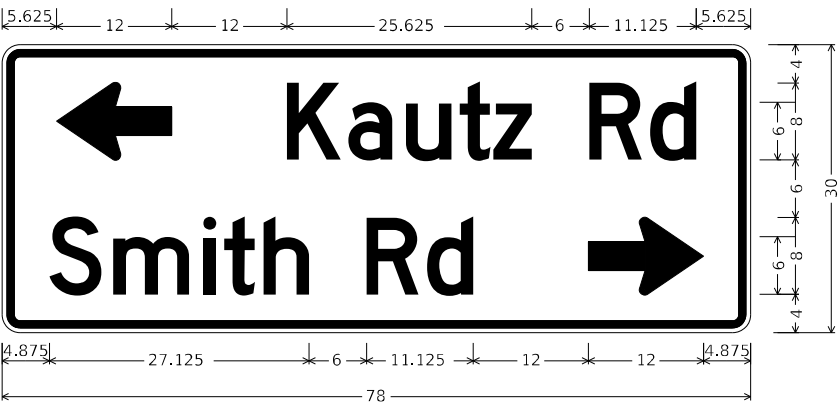

DESIGN SERIES	AREA (SQ FT)	SIGN PANEL TYPE	SHEETING TYPE	QTY. REQUIRED
D	16.25	2	ZZ	2

SCHEDULE OF QUANTITIES

ITEM DESCRIPTION	UNIT	QUANTITY
SIGN PANEL - TYPE 2	SQ FT	87.5
MAINTENANCE OF EXISTING TRAFFIC SIGNAL INSTALLATION	EACH	1
ELECTRIC CABLE IN CONDUIT, SIGNAL NO. 14 2C	FOOT	248
ELECTRIC CABLE IN CONDUIT, LEAD-IN, NO. 14 1 PAIR	FOOT	555
DRILL EXISTING HANDHOLE	EACH	1
INDUCTIVE LOOP DETECTOR	EACH	2
REMOVE EXISTING TRAFFIC SIGNAL EQUIPMENT	EACH	1
REMOVE EXISTING HANDHOLE	EACH	2
CLOSED CIRCUIT TELEVISION DOME CAMERA, HD	EACH	1
TERMINAL SERVER	EACH	1
LED LAMP MODULE REPLACEMENT	EACH	82
OUTDOOR RATED NETWORK CABLE	FOOT	221
REMOTE CONTROLLED VIDEO SYSTEM	EACH	1
TERMINATE FIBER IN CABINET	EACH	36
PEDESTRIAN SIGNAL POST, 5 FT.	EACH	1
LAYER III (NETWORK) SWITCH	EACH	1
TACTICS LICENSE EXPANSION	EACH	1
FULL-ACTUATED CONTROLLER IN EXISTING CABINET	EACH	1
REMOVE AND REPLACE BATTERIES FOR UNINTERRUPTABLE POWER SUPPLY, EXTENDED	EACH	1
FIBER OPTIC INTERCONNECT CENTER, 48 PORT	EACH	1
ACCESSIBLE PEDESTRIAN SIGNALS	EACH	4
CONCRETE FOUNDATION, TYPE A 12-INCH DIAMETER	FOOT	4
LED SIGNAL FACE, LENS COVER	EACH	22
LED PEDESTRIAN SIGNAL MODULE REPLACEMENT	EACH	12
VIDEO VEHICLE DETECTION SYSTEM, SINGLE APPROACH	EACH	2
CAMERA MOUNTING ASSEMBLY	EACH	1

TS 9023
IDOT TACTICS
FORMER EAGLE 2M

MODEL: Default
FILE: Kimley-Horn-Bentley.com\ktp\p4\11\Documents\01 Active Projects\IMW-CHS-168959\100 - IL 64\Phase III\2 Design\CAD\Plan Sheets\Sign\West Corridor Sign\IL64\Plan_Signs\IL64.dgn

KimleyHorn

© 2023 KIMLEY-HORN AND ASSOCIATES, INC.
4001 WILMINGTON ROAD, SUITE 600
WARREN, IL 60555
PHONE: 847.447.4555
WWW.KIMLEY-HORN.COM

USER NAME =
PLOT SCALE =
PLOT DATE =

DESIGNED -
DRAWN -
CHECKED -
DATE -

REVISED -
REVISED -
REVISED -
REVISED -

STATE OF ILLINOIS
DEPARTMENT OF TRANSPORTATION


SCHEDULE OF QUANTITIES
IL 64 (MAIN ST) AND SMITH RD/KAUTZ RD

SCALE: N.T.S. SHEET OF SHEETS STA. TO STA.

F.A.P. RTE.	SECTION	COUNTY	TOTAL SHEETS	SHEET NO.
307	2020-263-SUR,SW&TS	DUPAGE	529	109
CONTRACT NO. 62N33				
ILLINOIS FED. AID PROJECT				

NOTES

1. THE EXISTING TRAFFIC SIGNAL EQUIPMENT SHALL NOT BE REMOVED UNTIL THE PROPOSED TRAFFIC SIGNAL EQUIPMENT IS FULLY OPERATIONAL OR AS DIRECTED BY THE ENGINEER.
2. ALL EXISTING TRAFFIC SIGNAL CABLE NO LONGER REQUIRED SHALL BE REMOVED.

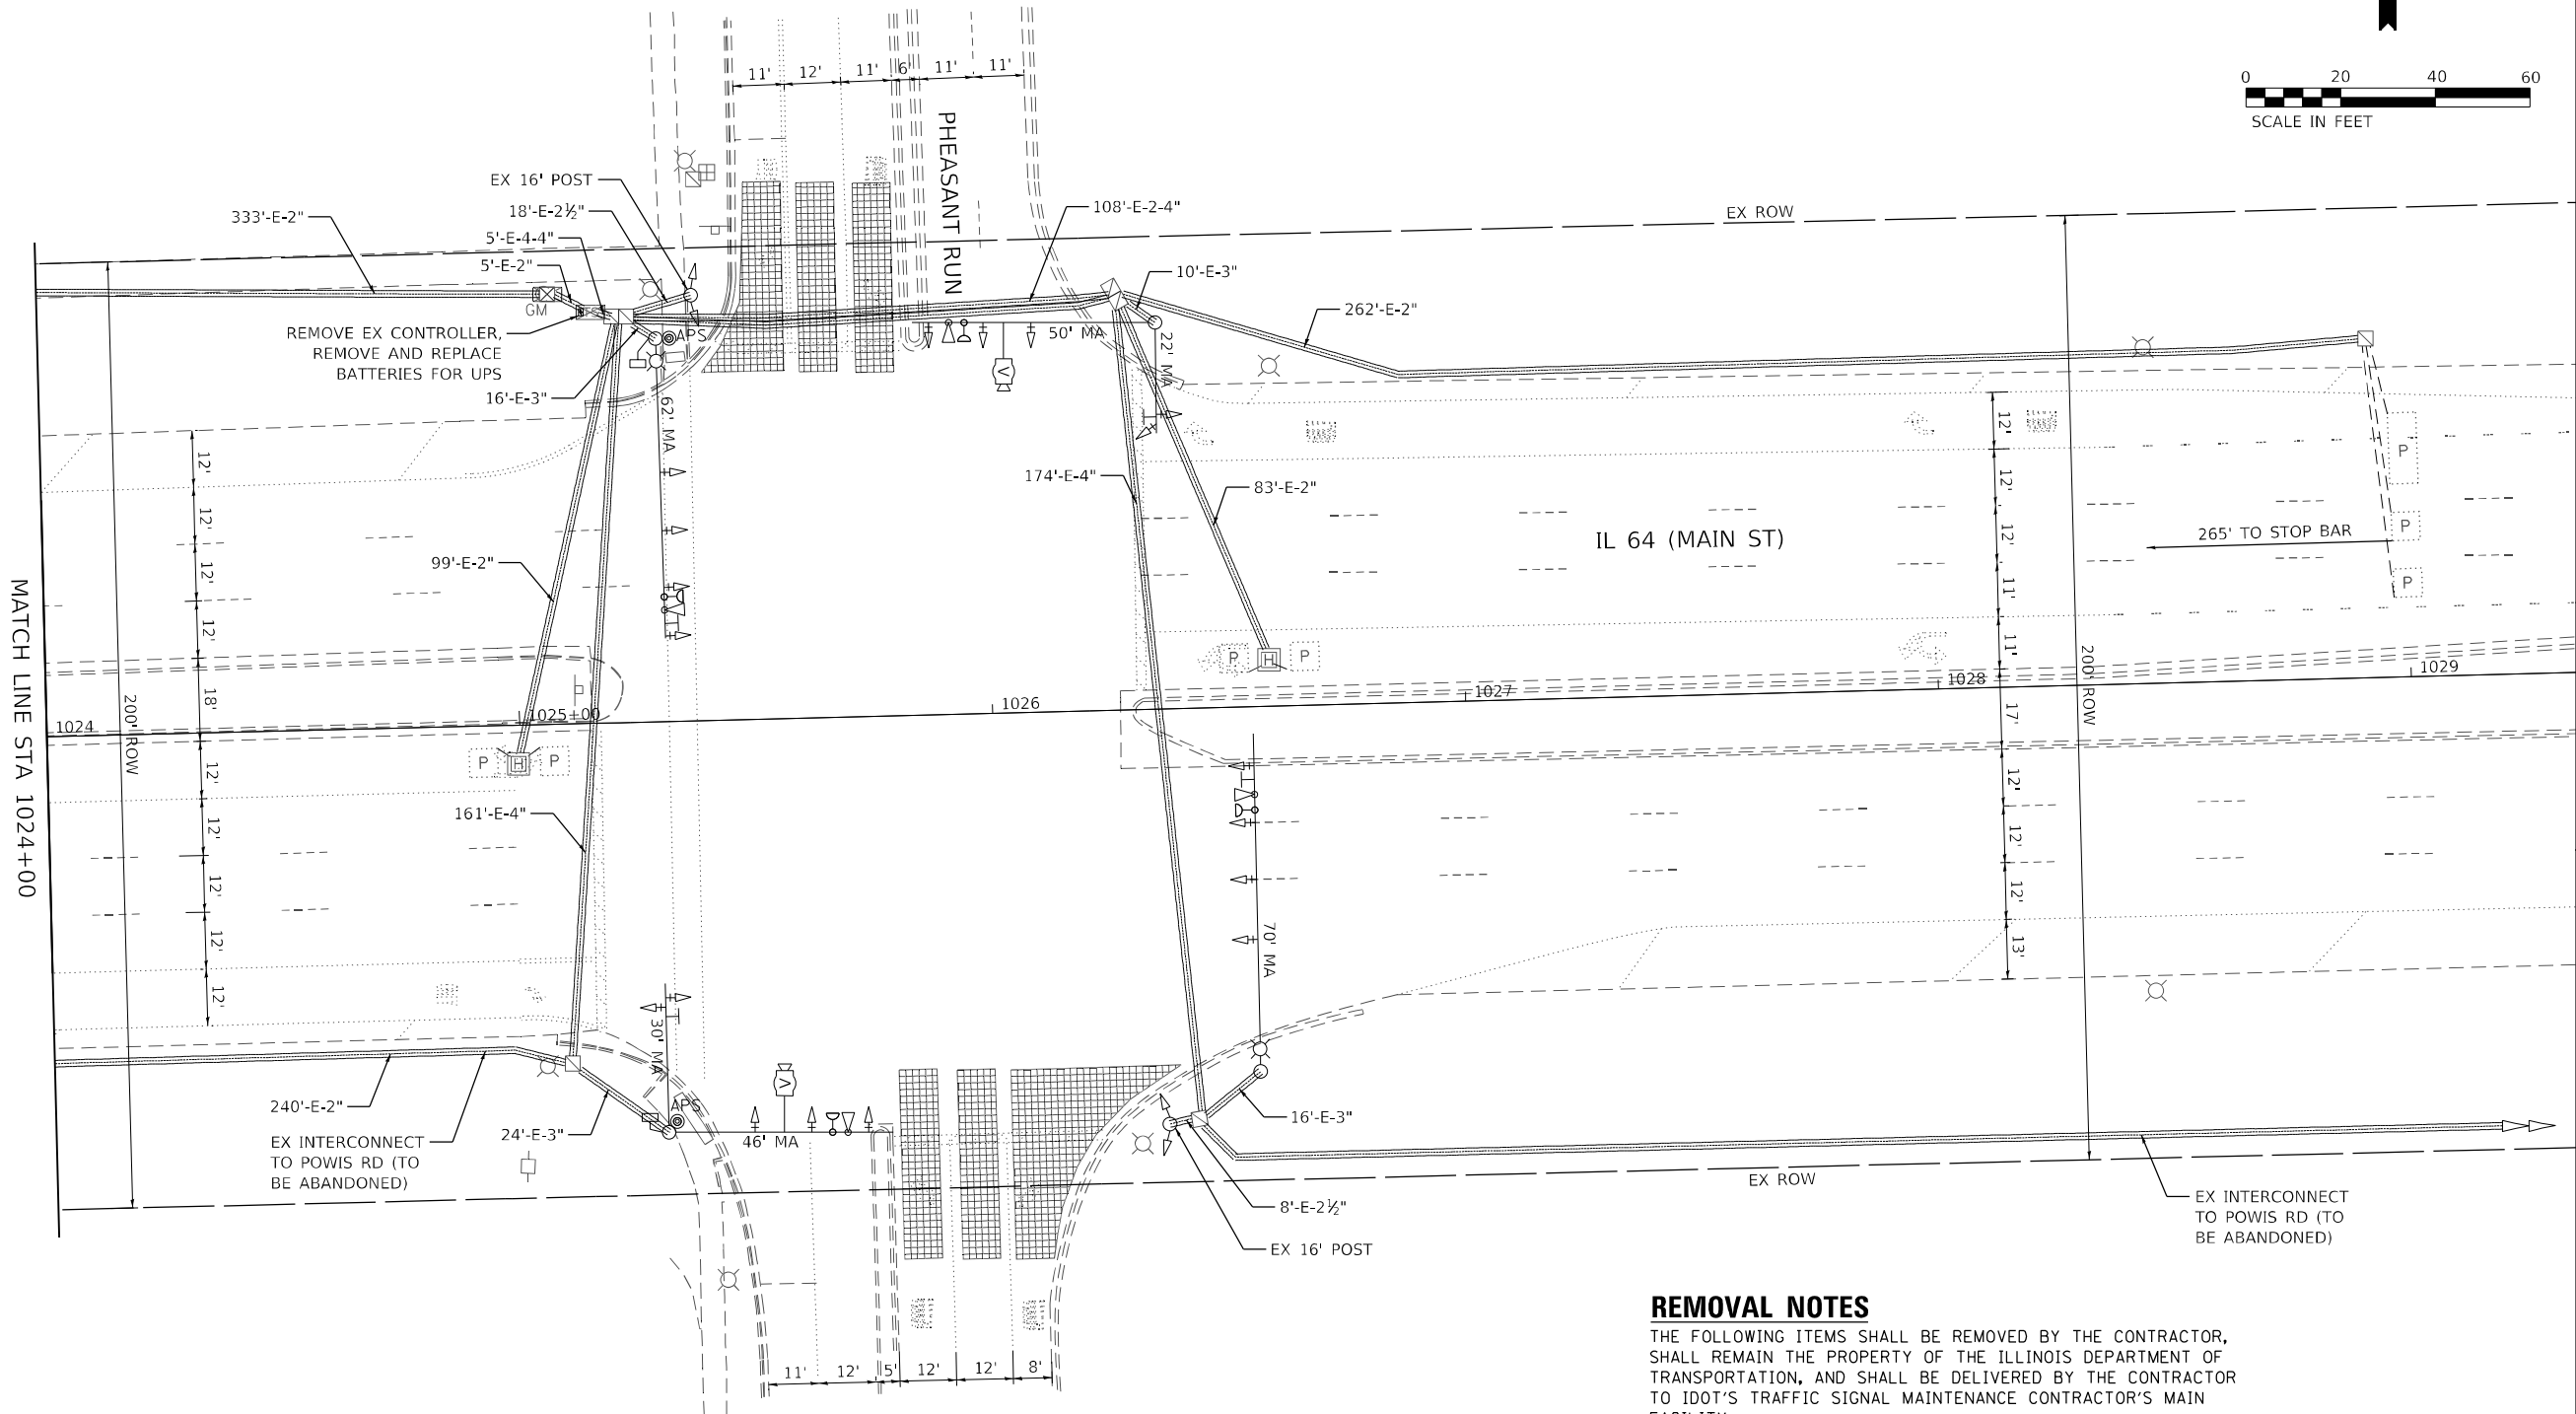

REMOVAL NOTES

THE FOLLOWING ITEMS SHALL BE REMOVED BY THE CONTRACTOR, SHALL REMAIN THE PROPERTY OF THE ILLINOIS DEPARTMENT OF TRANSPORTATION, AND SHALL BE DELIVERED BY THE CONTRACTOR TO IDOT'S TRAFFIC SIGNAL MAINTENANCE CONTRACTOR'S MAIN FACILITY.

1 EACH CONTROLLER (M52)

TS 9024
IDOT TACTICS
FORMER EAGLE 2M



© 2023 KIMLEY-HORN AND ASSOCIATES, INC.
4001 WILHELM D. ROAD, SUITE 600
WARREN, ILL. 60555
PHONE: (847) 455-4555
WWW.KIMLEY-HORN.COM



USER NAME =	DESIGNED -	REVISED -
	DRAWN -	REVISED -
PLOT SCALE =	CHECKED -	REVISED -
PLOT DATE =	DATE -	REVISED -

STATE OF ILLINOIS
DEPARTMENT OF TRANSPORTATION

TRAFFIC SIGNAL EQUIPMENT REMOVAL PLAN
IL 64 (MAIN ST) AND PHEASANT RUN

SCALE: 1" = 20' SHEET OF SHEETS STA. TO STA.

F.A.P. RTE.	SECTION	COUNTY	TOTAL SHEETS	SHEET NO.
307	2020-263-SUR, SW&TS	DUPAGE	529	110
				CONTRACT NO. 62N33
		ILLINOIS	FED. AID PROJECT	

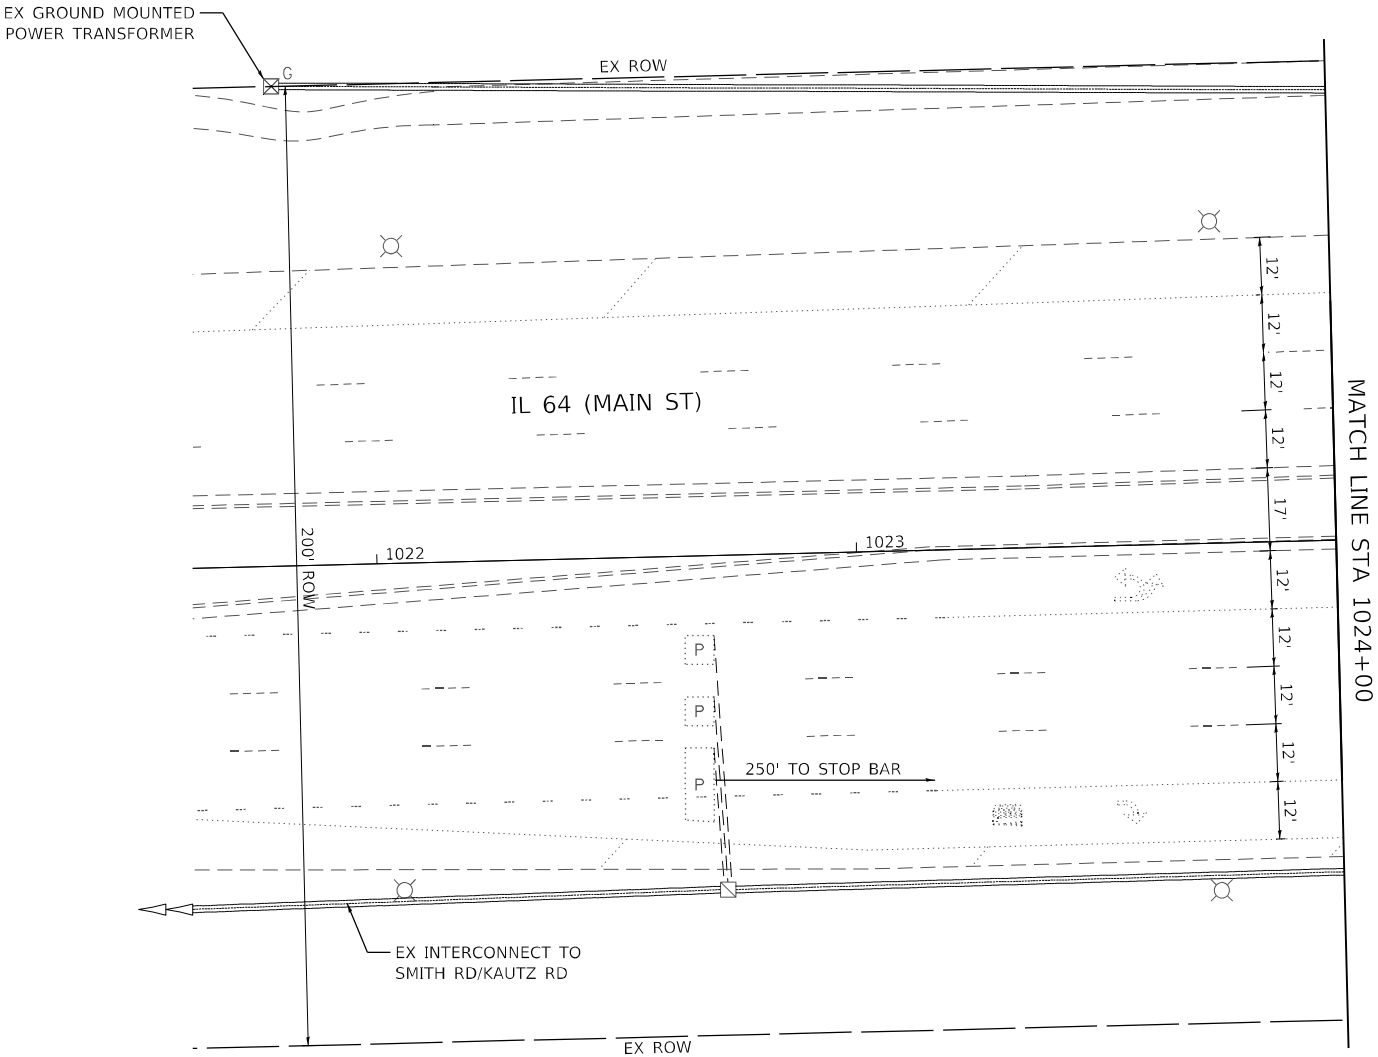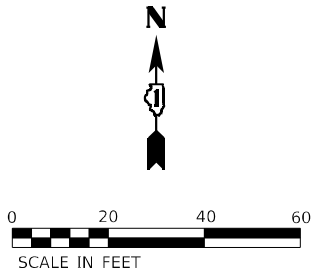

MODEL: Default
FILE NAME: p:\sub-pw\bartley.com\k-h-pw-d\Documents\01 Active Projects\MW\CHS-168950\00 - IL 64\Phase II\2 Design\CAD\Plan Sheets\Signal\West Corridor_Signal\01081714-IL-64-K4A.dgn



USER NAME =	DESIGNED -	REVISED -
	DRAWN -	REVISED -
PLOT SCALE =	CHECKED -	REVISED -
PLOT DATE =	DATE -	REVISED -

STATE OF ILLINOIS
DEPARTMENT OF TRANSPORTATION


TRAFFIC SIGNAL EQUIPMENT REMOVAL PLAN
IL 64 (MAIN ST) AND PHEASANT RUN

SCALE: 1" = 20' SHEET OF SHEETS STA. TO STA.

F.A.P. RTE.	SECTION	COUNTY	TOTAL SHEETS	SHEET NO.
307	2020-263-SUR, SW&TS	DUPAGE	529	111
CONTRACT NO. 62N33				
		ILLINOIS	FED. AID PROJECT	

TS 9024
IDOT TACTICS
FORMER EAGLE 2M

A

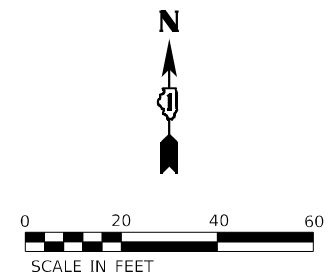

1. ALL PROPOSED TRAFFIC SIGNAL CABLE SHALL BE ROUTED THROUGH THE PROPOSED CONDUIT.
2. A SEPARATE LEAD-IN CABLE SHALL BE INSTALLED FOR THE DETECTOR LOOPS ON IL 64 (NORTH AVE).
3. THERE SHALL BE A MINIMUM OF 4' SIDEWALK CLEARANCE IN FRONT/BEHIND OF THE TRAFFIC SIGNAL FOUNDATIONS TO BE ADA COMPLIANT.
4. THE SIDEWALK CURBS ON ALL QUADRANTS SHALL BE CUT SO THAT THE POST AND MAST ARM FOUNDATIONS ARE FLUSH WITH THE EDGE OF THE SIDEWALK.
5. ALL PUSH BUTTONS SHALL BE APS.
6. THIS LOCATION HAS BEEN DESIGNED TO BE ADA COMPLIANT. ANY DEVIATION FROM THIS PLAN FOR THE POSTS THAT HAVE PEDESTRIAN EQUIPMENT WILL HAVE TO BE APPROVED BY THE ENGINEER TO ENSURE ADA COMPLIANCE.
7. CONTRACTOR SHALL VERIFY THAT THE PLACEMENT OF THE PROPOSED SIGNAL EQUIPMENT ADJACENT TO EXISTING RAMPS MEET ADA REQUIREMENTS. THE ENGINEER SHALL APPROVE THE PROPOSED LOCATIONS OF THE SIGNAL EQUIPMENT BEFORE INSTALLATION.

TS 9024

IDOT TACTICS

FORMER EAGLE 2M



Kimley»Horn

© 2023 KIMLEY-HORN AND ASSOCIATES, INC.
4201 WILDFIELD ROAD, SUITE 603
WARRENVILLE, IL 60555
PHONE: 630-487-6550
WWW.KIMLEY-HORN.COM

**STATE OF ILLINOIS
DEPARTMENT OF TRANSPORTATION**

**TRAFFIC SIGNAL MODERNIZATION PLAN
IL 64 (MAIN ST) AND PHEASANT RUN**

SCALE: 1" = 20'	SHEET	OF	SHEETS	STA.	TO STA.
-----------------	-------	----	--------	------	---------

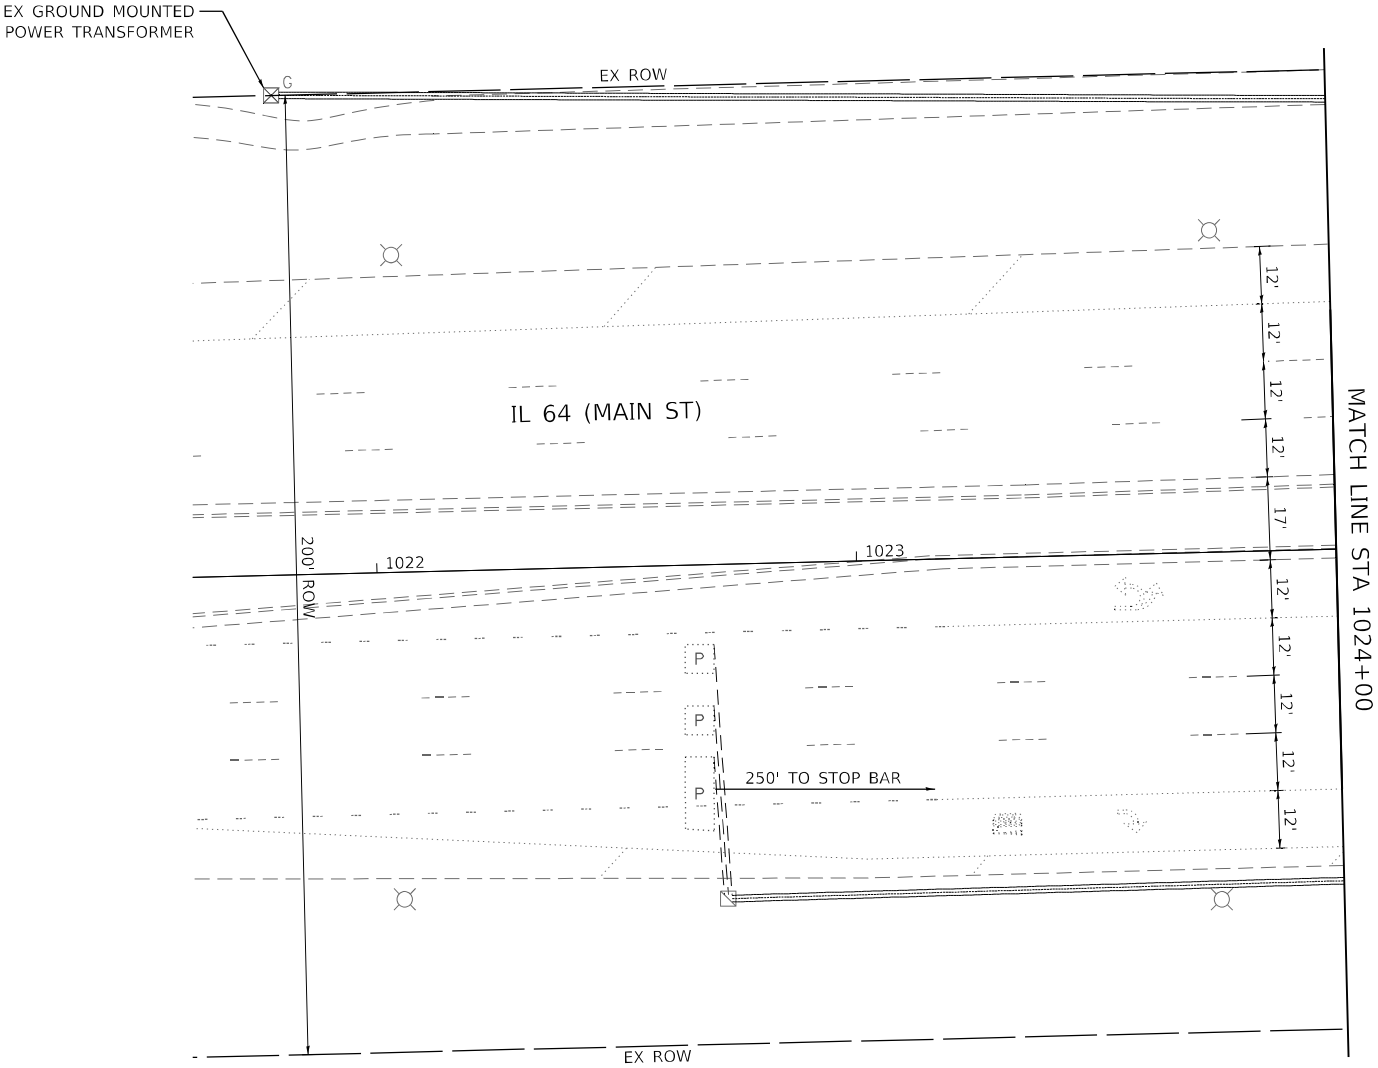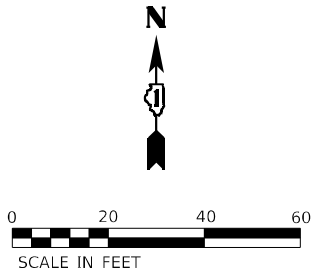

MODEL: Default
FILE NAME: p:\sub-pw\bartley.com\k-h-pw-d\Documents\01 Active Projects\MW-CL-S-168950\00 - IL 64\Phase II\2 Design\CAD\Plan Sheets\Signal\West Corridor_Signal\01 IL 64-10_K4A.dgn



USER NAME =	DESIGNED -	REVISED -
	DRAWN -	REVISED -
PLOT SCALE =	CHECKED -	REVISED -
PLOT DATE =	DATE -	REVISED -

STATE OF ILLINOIS
DEPARTMENT OF TRANSPORTATION


TRAFFIC SIGNAL MODERNIZATION PLAN
IL 64 (MAIN ST) AND PHEASANT RUN

SCALE: 1" = 20' SHEET OF SHEETS STA. TO STA.

F.A.P. RTE.	SECTION	COUNTY	TOTAL SHEETS	SHEET NO.
307	2020-263-SUR, SW&TS	DUPAGE	529	113
CONTRACT NO. 62N33				
ILLINOIS FED. AID PROJECT				

TS 9024
IDOT TACTICS
FORMER EAGLE 2M

EXISTING AND PROPOSED
CONTROLLER SEQUENCE

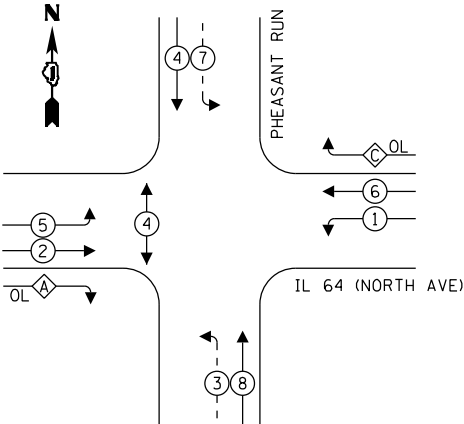


LEGEND:

- ← (*) PROTECTED PHASE
- ← (*) - PROTECTED/PERMITTED PHASE
- ← (*) → PEDESTRIAN PHASE
- ← (*) OL OVERLAP

OVERLAP LETTER	PERMISSIVE PHASE	PROTECTED PHASE
A	= 2	+ 3
C	= 6	+ 7

EXISTING AND PROPOSED EMERGENCY
VEHICLE PREEMPTION SEQUENCE

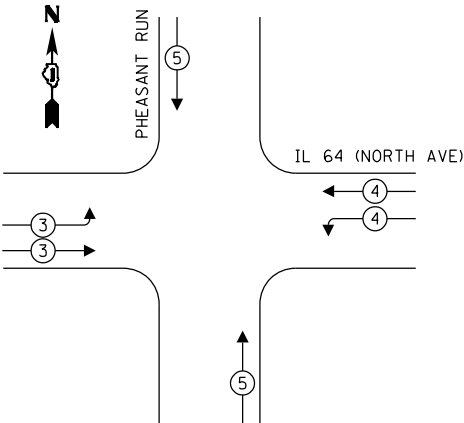

TRAFFIC SIGNAL
ELECTRICAL SERVICE REQUIREMENTS

TYPE	QUANTITY	UNIT WATTAGE	TOTAL WATTAGE
SIGNAL HEAD 1 OR 3-SECTION	14	11	154
4-SECTION	-	14	-
5-SECTION	8	13	104
PROGRAMMABLE 3-SECTION	-	22	-
4-SECTION	-	32	-
5-SECTION	-	28	-
PEDESTRIAN SIGNAL	2	15	30
CONTROLLER	1	150	150
MASTER CONTROLLER	-	100	-
UPS	1	25	25
DETECTION VIDEO	2	20	40
BLANK-OUT SIGN	-	25	-
NETWORK SWITCH LAYER II OR III	1	35	35
CELLULAR MODEM	-	15	-
PTZ	-	75	-
TOTAL UPS SIZING			538
UPS CHARGING	1	225	225
BATTERY HEATER MAT	1	180	180
CABINET HEATER	1	200	200
FLASHER	-	15	-
LED STREET NAME SIGN	-	120	-
LUMINAIRE	-	240	-
TOTAL SERVICE WIRE SIZING			1143


ENERGY COSTS TO:
CITY OF ST. CHARLES
2 E MAIN ST
ST. CHARLES, IL 60174

ENERGY SUPPLY: CONTACT: STEVE SHROBA
PHONE: (630) 377-4475
ACCOUNT NUMBER: _____

LEGEND:

- L = LED LAMP MODULE REPLACEMENT
- * = ROADWAY LIGHTING CABLE

CABLE PLAN
(NOT TO SCALE)

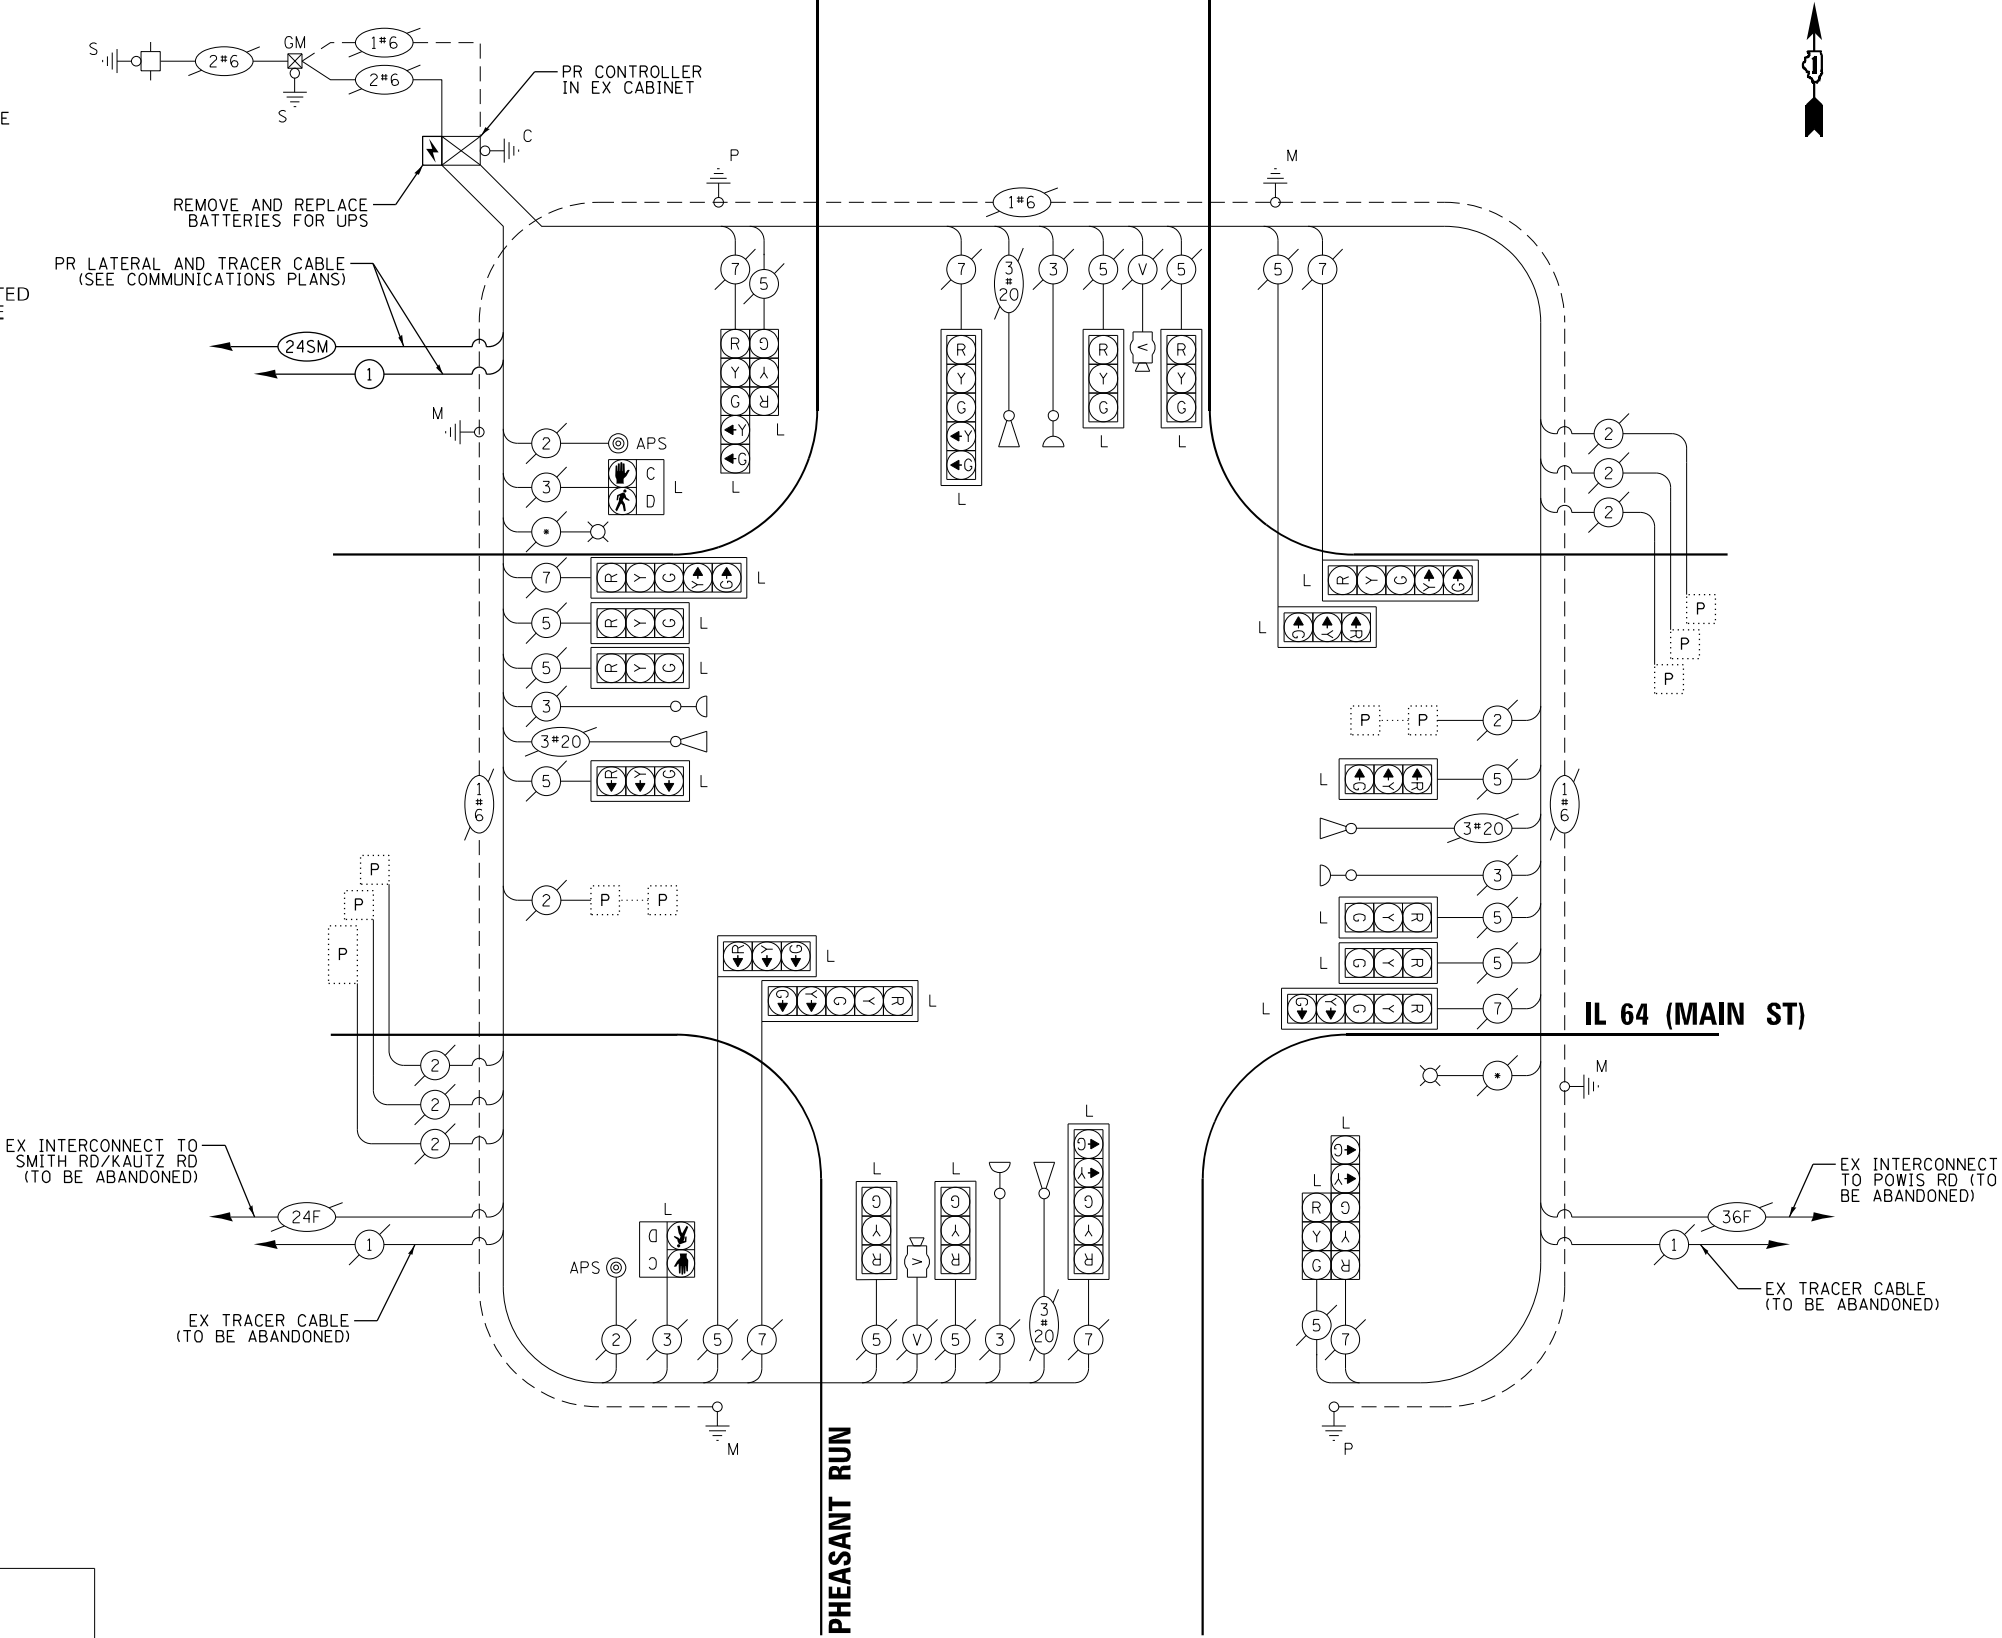

STATE OF ILLINOIS
DEPARTMENT OF TRANSPORTATION

CABLE PLAN, PHASE DESIGNATION DIAGRAM, AND
EMERGENCY VEHICLE PREEMPTION SEQUENCE
IL 64 (MAIN ST) AND PHEASANT RUN

SCALE: N.T.S. SHEET OF SHEETS STA. TO STA.

F.A.P. RTE.	SECTION	COUNTY	TOTAL SHEETS	SHEET NO.
307	2020-263-SUR, SW&TS	DUPAGE	529	114
CONTRACT NO. 62N33				
ILLINOIS FED. AID PROJECT				

TS 9024
IDOT TACTICS
FORMER EAGLE 2M

KimleyHorn

© 2023 KIMLEY-HORN AND ASSOCIATES, INC.
4001 WILSON D. ROAD, SUITE 600
WARREN, ILL. 60555
PHONE: (630) 477-4555
WWW.KIMLEY-HORN.COM

USER NAME =	DESIGNED -	REVISED -
PLOT SCALE =	DRAWN -	REVISED -
PLOT DATE =	CHECKED -	REVISED -
	DATE -	REVISED -

SIGN PANEL – TYPE 2

ALL DIMENSIONS ARE IN INCHES UNLESS OTHERWISE NOTED



DESIGN SERIES	AREA (SQ. FT)	SIGN PANEL TYPE	SHEETING TYPE	QTY. REQUIRED
D	11.25	2	ZZ	2

SCHEDULE OF QUANTITIES

ITEM DESCRIPTION	UNIT	QUANTITY
SIGN PANEL - TYPE 2	SQ. FT.	22.5
MAINTENANCE OF EXISTING TRAFFIC SIGNAL INSTALLATION	EACH	1
REMOVE EXISTING TRAFFIC SIGNAL EQUIPMENT	EACH	1
LED LAMP MODULE REPLACEMENT	EACH	82
LAYER II (DATALINK) SWITCH	EACH	1
TACTICS LICENSE EXPANSION	EACH	1
FULL-ACTUATED CONTROLLER IN EXISTING CABINET	EACH	1
REMOVE AND REPLACE BATTERIES FOR UNINTERRUPTABLE POWER SUPPLY, EXTENDED	EACH	1
FIBER OPTIC INTERCONNECT CENTER, 48 PORT	EACH	1
ACCESSIBLE PEDESTRIAN SIGNALS	EACH	2
LED SIGNAL FACE, LENS COVER	EACH	22
LED PEDESTRIAN SIGNAL MODULE REPLACEMENT	EACH	6
TERMINATE FIBER IN CABINET	EACH	12

TS 9024
IDOT TACTICS
FORMER EAGLE 2M

Model: Default
File: Name: p:\sub-pw-bentley.com\ktp-pw-d\Documents\01 Active Projects\MMW-CL-S-160950\00 - IL 64\Phase 01\2 Design\CAD\Plan Sheets\Sign\InWest Corridor_Signs\BID\081714\InRte-12_KIM.dgn



© 2023 KIMLEY-HORN AND ASSOCIATES, INC.
4001 HWY 10, SUITE 600
WARREN, IL 60555
PHONE: 815.447.4555
WWW.KIMLEY-HORN.COM

USER NAME =	DESIGNED -	REVISED -
	DRAWN -	REVISED -
PLOT SCALE =	CHECKED -	REVISED -
PLOT DATE =	DATE -	REVISED -

STATE OF ILLINOIS
DEPARTMENT OF TRANSPORTATION

MAST ARM MOUNTED STREET NAME SIGNS AND
SCHEDULE OF QUANTITIES
IL 64 (MAIN ST) AND PHEASANT RUN




SCALE: N.T.S.

SHEET OF SHEETS

STA. TO STA.

F.A.P. RTE.	SECTION	COUNTY	TOTAL SHEETS	SHEET NO.
307	2020-263-SUR, SW&TS	DUPAGE	529	115
CONTRACT NO. 62N33				
ILLINOIS FED. AID PROJECT				

MODEL: Default
FILE: \\kimley-horn-bentley.com\khp\p4\11\Documents\01 Active Projects\IMW\CHS-16895\000 - IL 64\Phase 1\12 Design\CAD\Plan_Sheets\Signal\West_Corridor_Signals\01081714\14-14-14_KIM.dgn

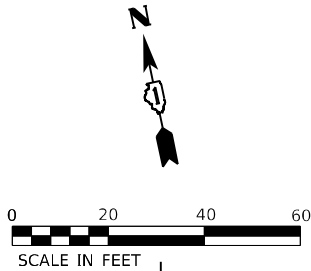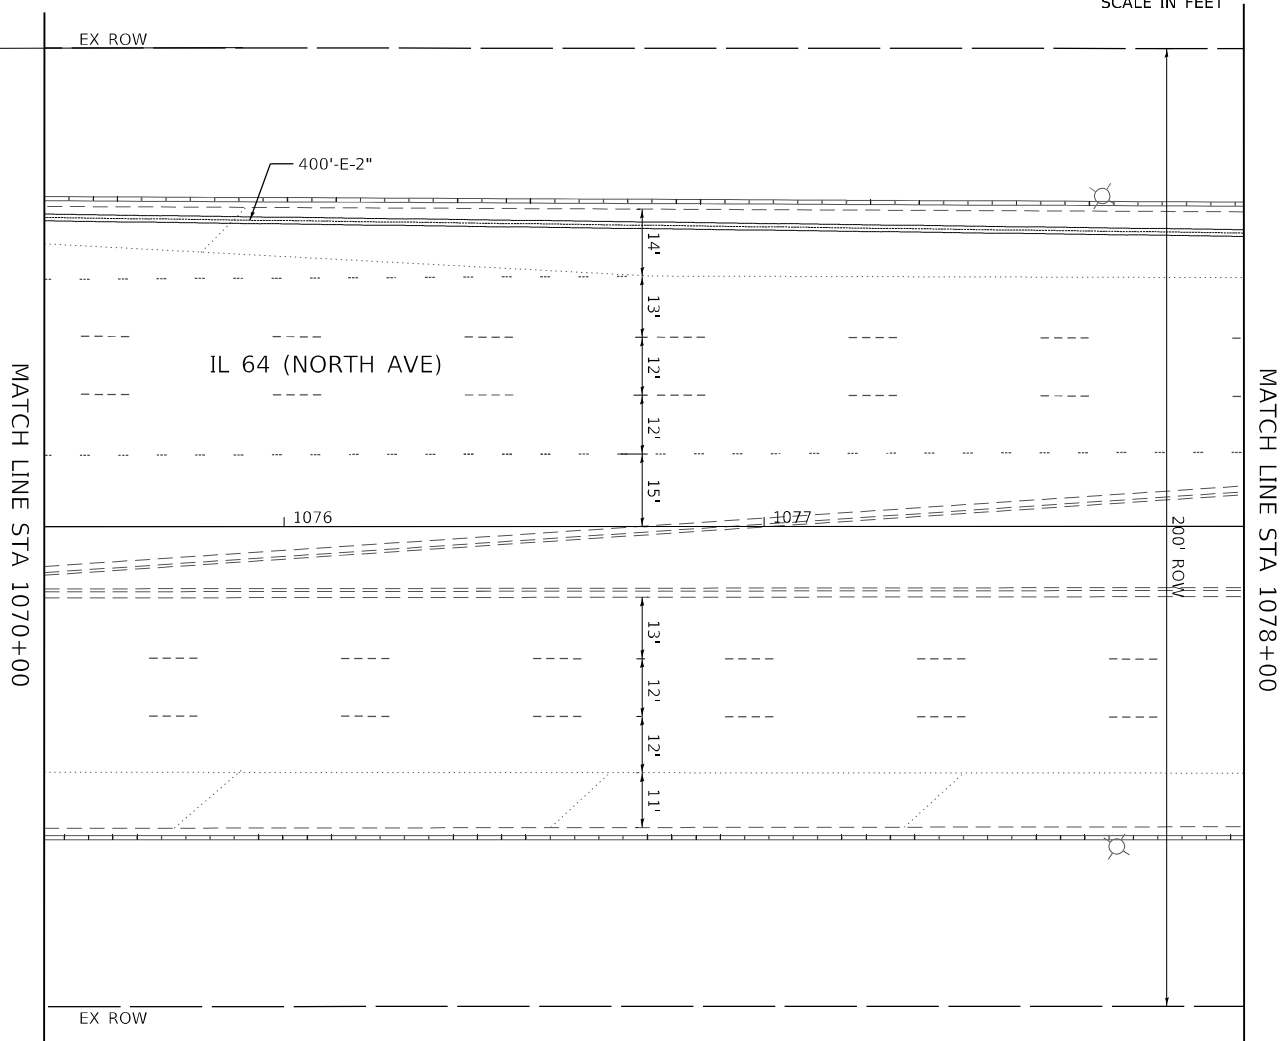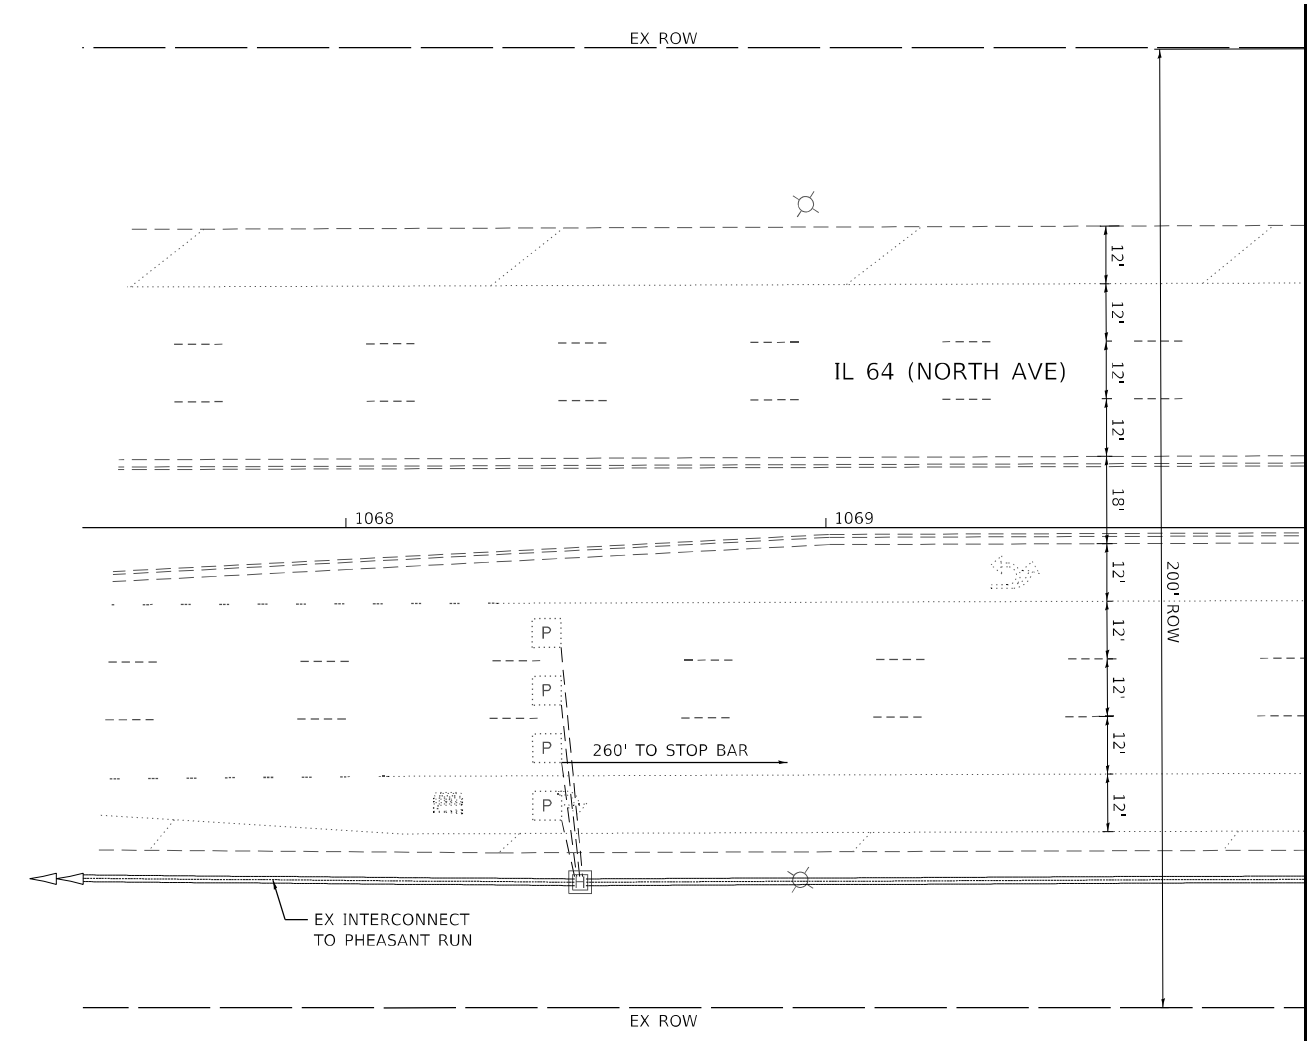



USER NAME =	DESIGNED -	REVISED -
DRAWN -	REVIS	REVIS
PLOT SCALE =	CHECKED -	REVISED -
PLOT DATE =	DATE -	REVISED -

STATE OF ILLINOIS
DEPARTMENT OF TRANSPORTATION

TRAFFIC SIGNAL EQUIPMENT REMOVAL PLAN			
IL 64 (NORTH AVE) AND POWIS RD			
SCALE: 1" = 20'	SHEET	OF	SHEETS
STA.	TO	STA.	TO


F.A.P. RTE.	SECTION	COUNTY	TOTAL SHEETS	SHEET NO.
307	2020-263-SUR,SW&TS	DUPAGE	529	117
CONTRACT NO. 62N33				
ILLINOIS FED. AID PROJECT				

TS 12070
IDOT TACTICS
FORMER EAGLE 2M

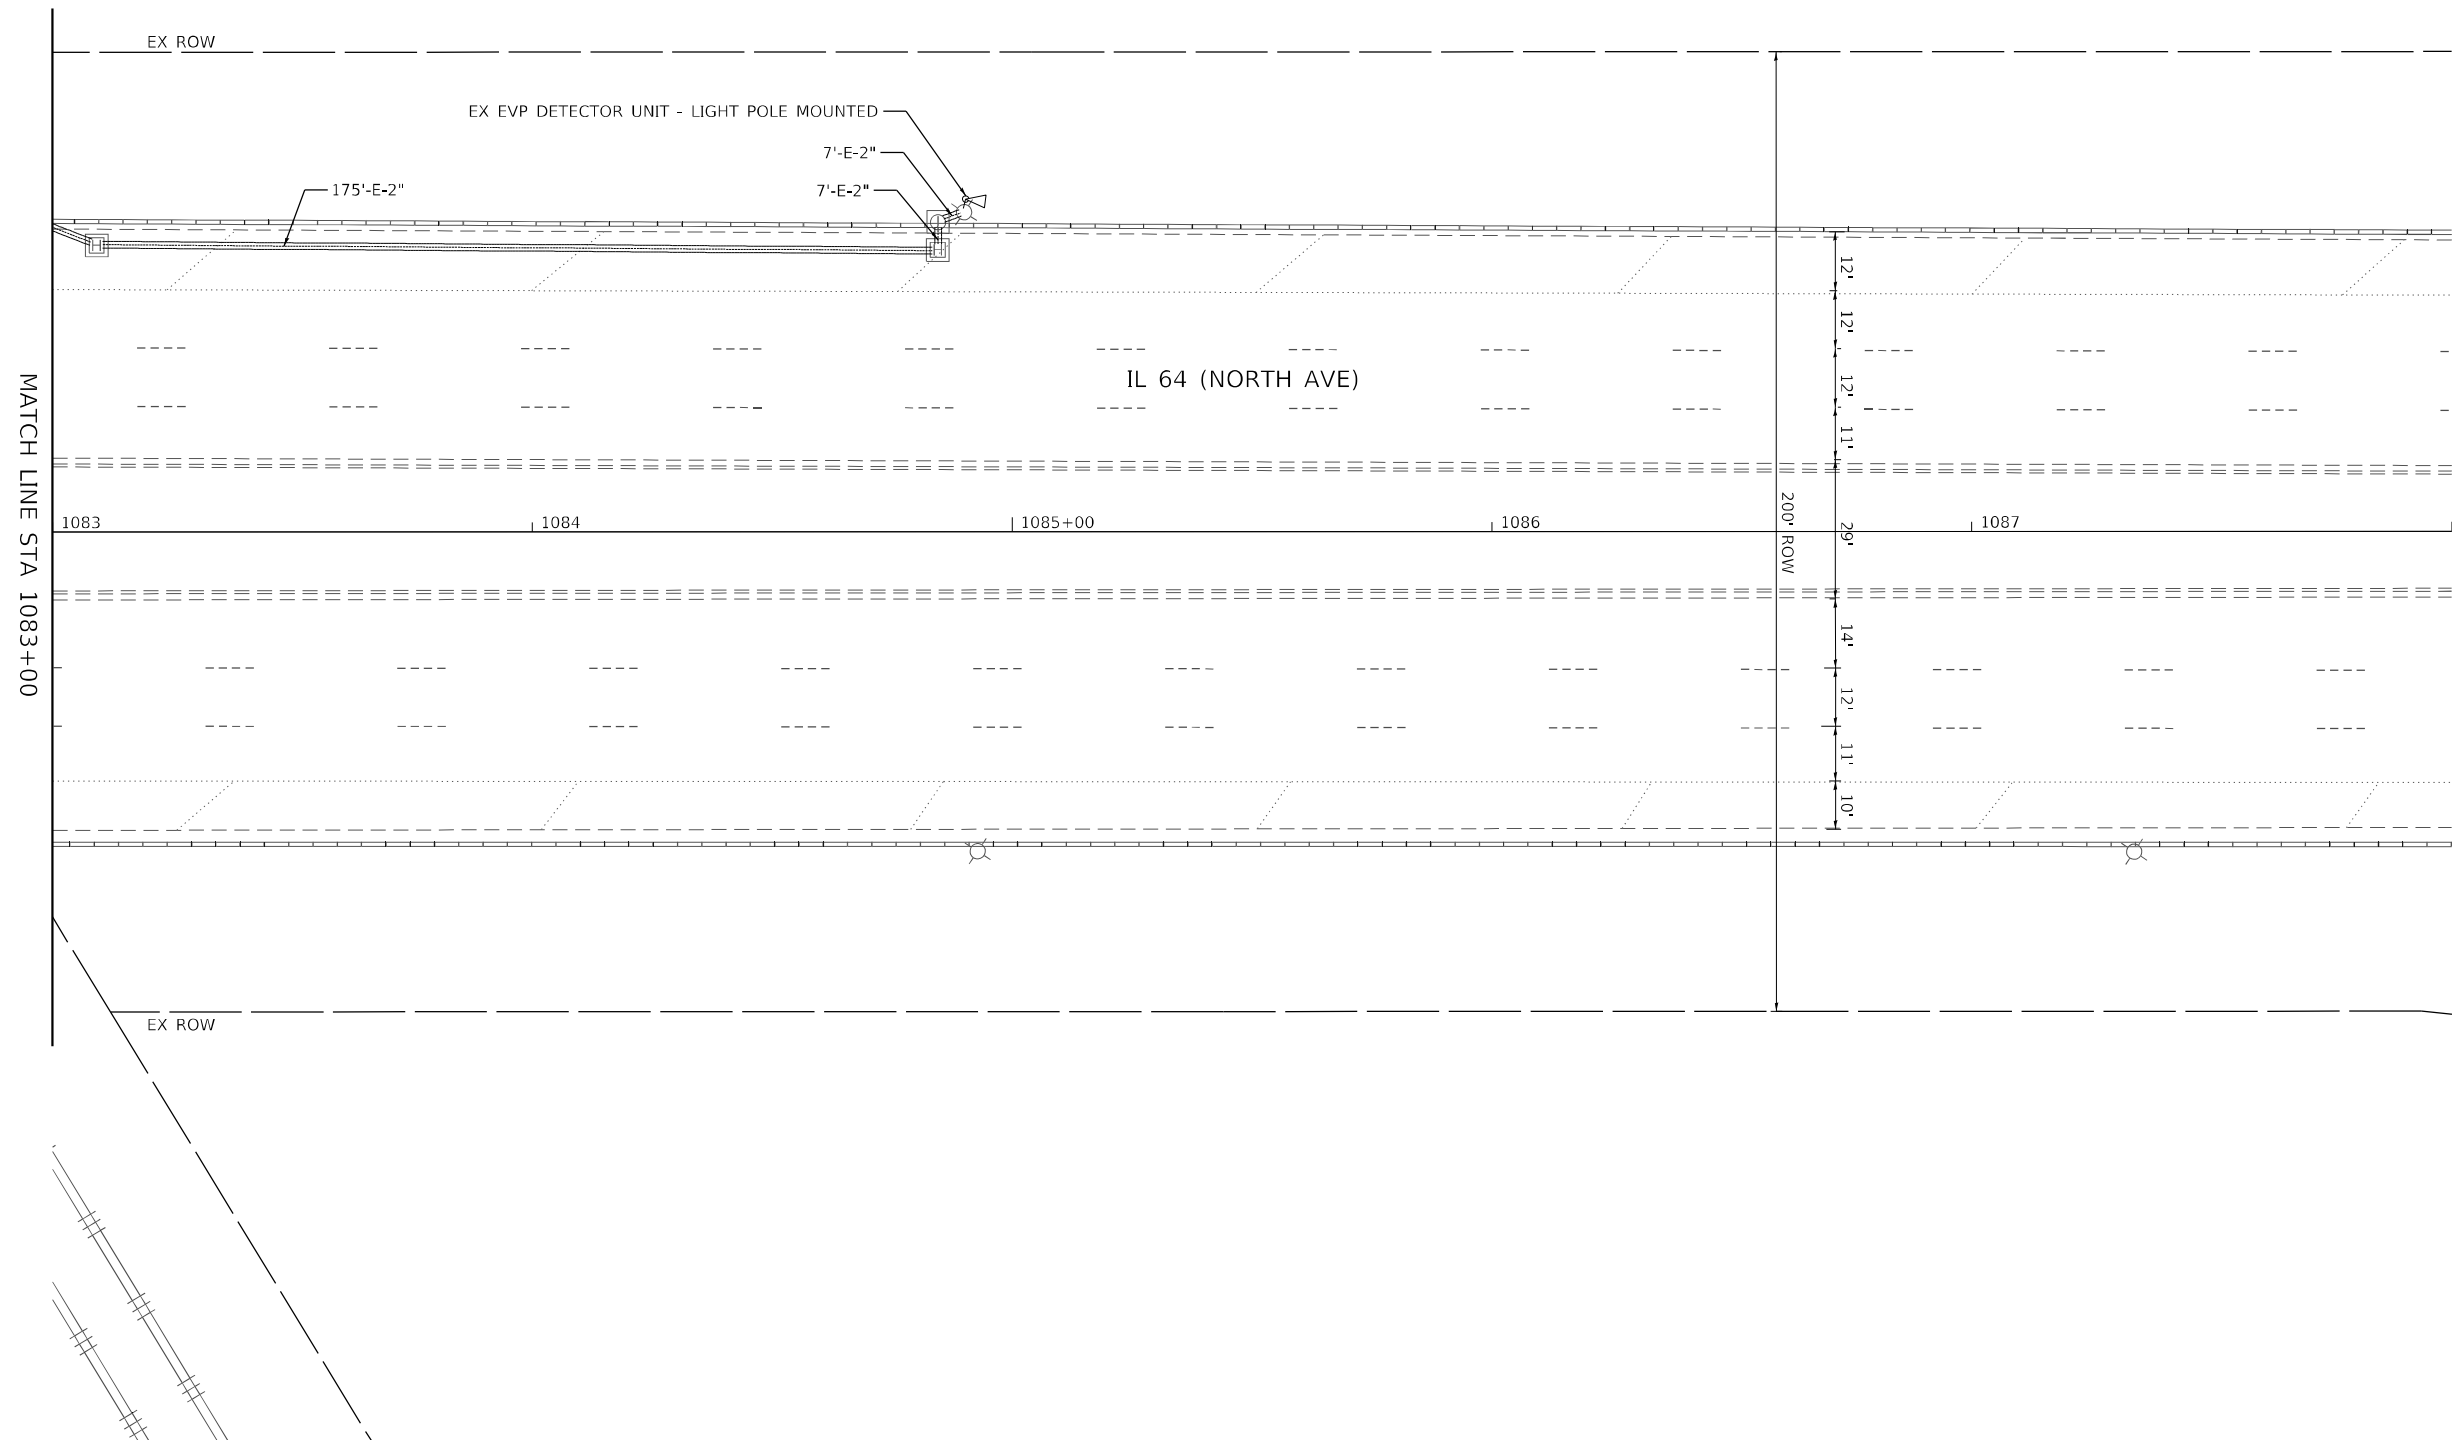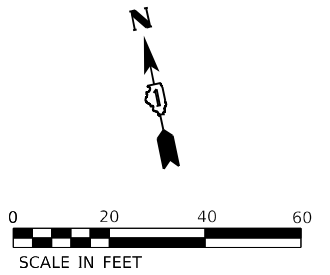

TS 12070
IDOT TACTICS
FORMER EAGLE 2M

MODEL: D:\road\2020\2020-263-SUR\2020-263-SUR.dwg KimleyHorn © 2022 KIMLEY-HORN AND ASSOCIATES, INC. 4001 VIBRTE, D. ROAD, SUITE 600 HARRISBURG, PA. 17105 PHONE: 717-637-6500 WWW.KIMLEY-HORN.COM	USER NAME =	DESIGNED -	REVISED -	STATE OF ILLINOIS DEPARTMENT OF TRANSPORTATION	TRAFFIC SIGNAL EQUIPMENT REMOVAL PLAN				F.A.P. RTE.	SECTION	COUNTY	TOTAL SHEETS	SHEET NO.
		DRAWN -	REVISED -		IL 64 (NORTH AVE) AND POWIS RD				307'	2020-263-SUR,SW&TS	DUPAGE	529	119
	PLOT SCALE =	CHECKED -	REVISED -		CONTRACT NO. 62N33								
	PLOT DATE =	DATE -	REVISED -		SCALE: 1" = 20'	SHEET	OF	SHEETS	STA.	TO STA.	ILLINOIS	FED. AID PROJECT	

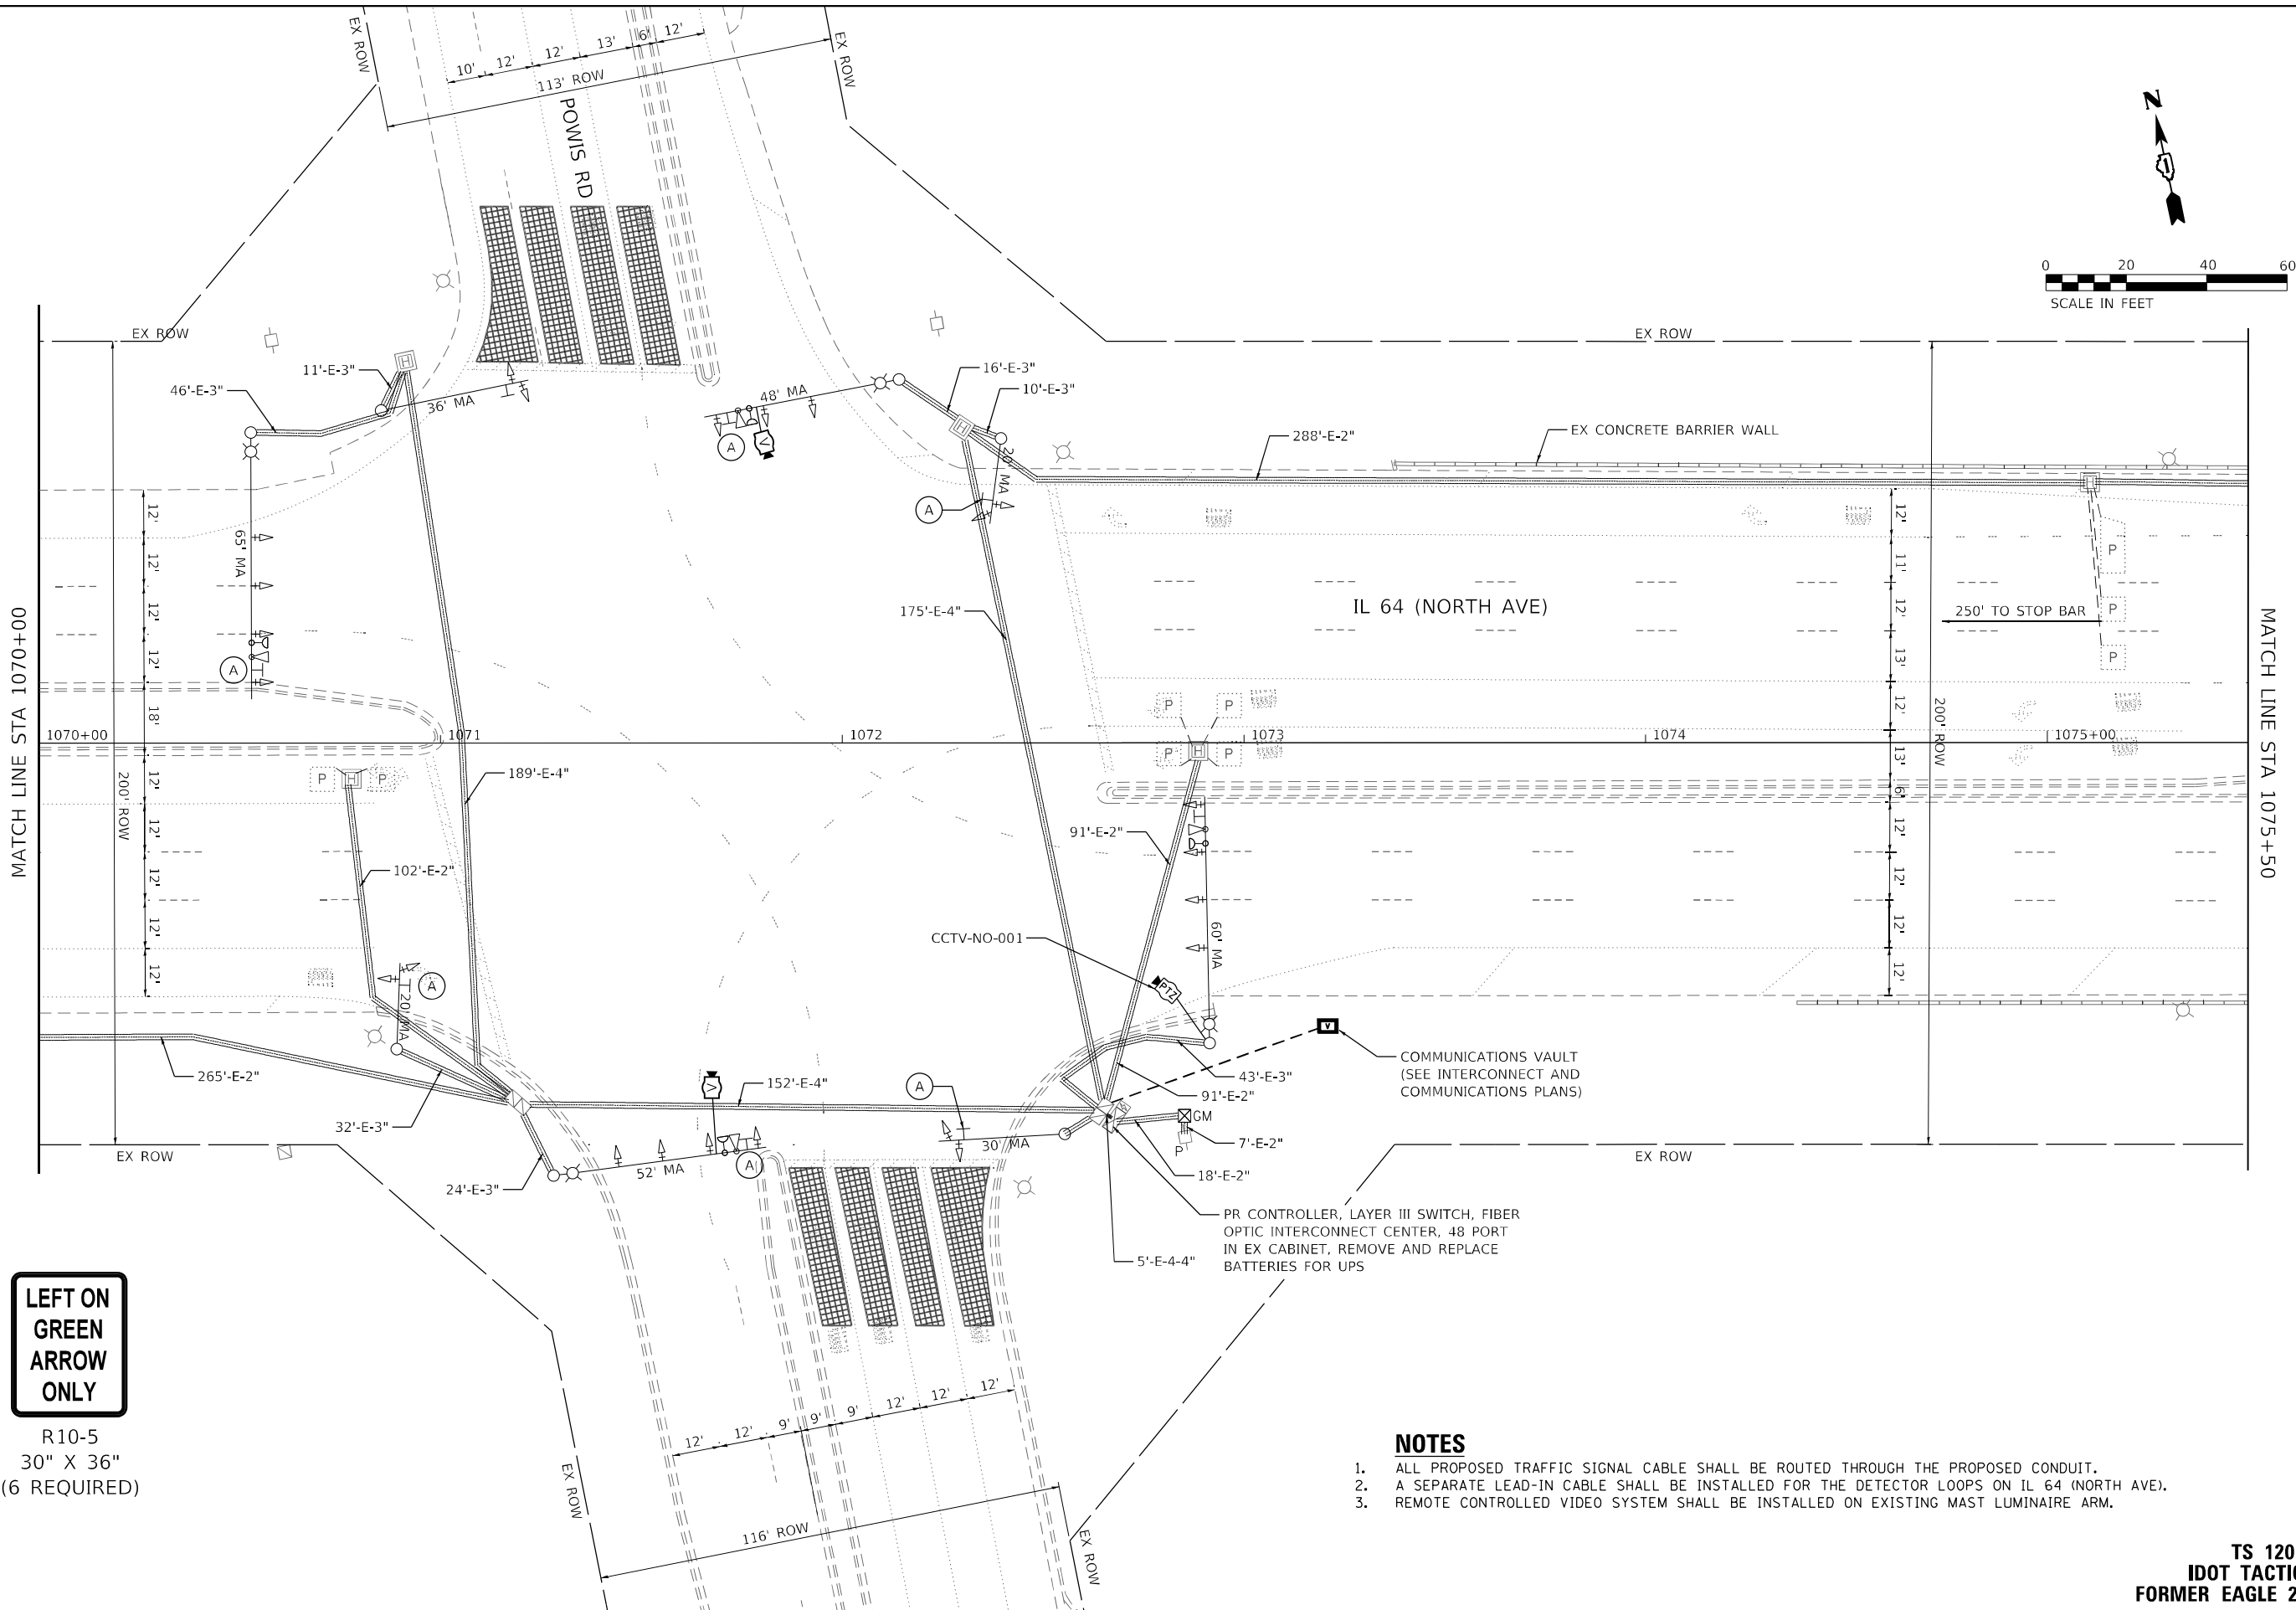

**LEFT ON GREEN
ARROW
ONLY**

R10-5
30" X 36"
(6 REQUIRED)

- NOTES**
1. ALL PROPOSED TRAFFIC SIGNAL CABLE SHALL BE ROUTED THROUGH THE PROPOSED CONDUIT.
 2. A SEPARATE LEAD-IN CABLE SHALL BE INSTALLED FOR THE DETECTOR LOOPS ON IL 64 (NORTH AVE).
 3. REMOTE CONTROLLED VIDEO SYSTEM SHALL BE INSTALLED ON EXISTING MAST LUMINAIRE ARM.

**TS 12070
IDOT TACTICS
FORMER EAGLE 2M**

KimleyHorn

© 2021 KIMLEY-HORN AND ASSOCIATES, INC.
4001 WILSON ROAD, SUITE 600
WARREN, IL 60555
PHONE: (847) 455-4555
WWW.KIMLEY-HORN.COM

USER NAME =	DESIGNED -	REVISED -
	DRAWN -	REVISED -
PLOT SCALE =	CHECKED -	REVISED -
PLOT DATE =	DATE -	REVISED -

**STATE OF ILLINOIS
DEPARTMENT OF TRANSPORTATION**

**TRAFFIC SIGNAL MODERNIZATION PLAN
IL 64 (NORTH AVE) AND POWIS RD**

SCALE: 1" = 20' SHEET OF SHEETS STA. TO STA.

F.A.P. RTE.	SECTION	COUNTY	TOTAL SHEETS	SHEET NO.
307	2020-263-SUR, SW&TS	DUPAGE	529	120
CONTRACT NO. 62N33				
ILLINOIS FED. AID PROJECT				

MODEL: Default
FILE: \\naulpc-prod\h-pw-bentley.com\h-pw-d\1\Documents\01 Active Projects\MW\CHS-16895\000 - IL 64\Phase 1\12 Design\CAD\Plan Streets\Signal\West Corridor Signal\01081714-14-14-18_KIM.dgn

Kimley»Horn

© 2021 KIMLEY-HORN AND ASSOCIATES, INC.
4001 WHITE OAK ROAD, SUITE 600
WARREN, ILL. 60555
PHONE: 847.477.4555
WWW.KIMLEY-HORN.COM




USER NAME	=	DESIGNED	-
		DRAWN	-
PLOT SCALE	=	CHECKED	-
PLOT DATE	=	DATE	-
		REVISED	-
		REVISED	-
		REVISED	-
		REVISED	-



STATE OF ILLINOIS
DEPARTMENT OF TRANSPORTATION

TRAFFIC SIGNAL MODERNIZATION PLAN			
IL 64 (NORTH AVE) AND POWIS RD			
SCALE: 1" = 20'	SHEET	OF	SHEETS
	STA.	TO	STA.

F.A.P. RTE.	SECTION	COUNTY	TOTAL SHEETS	SHEET NO.
307	2020-263-SUR, SW&TS	DUPAGE	529	121
CONTRACT NO. 62N33				
		ILLINOIS	FED. AID PROJECT	

TS 12070
IDOT TACTICS
FORMER EAGLE 2M

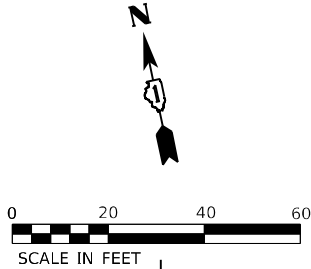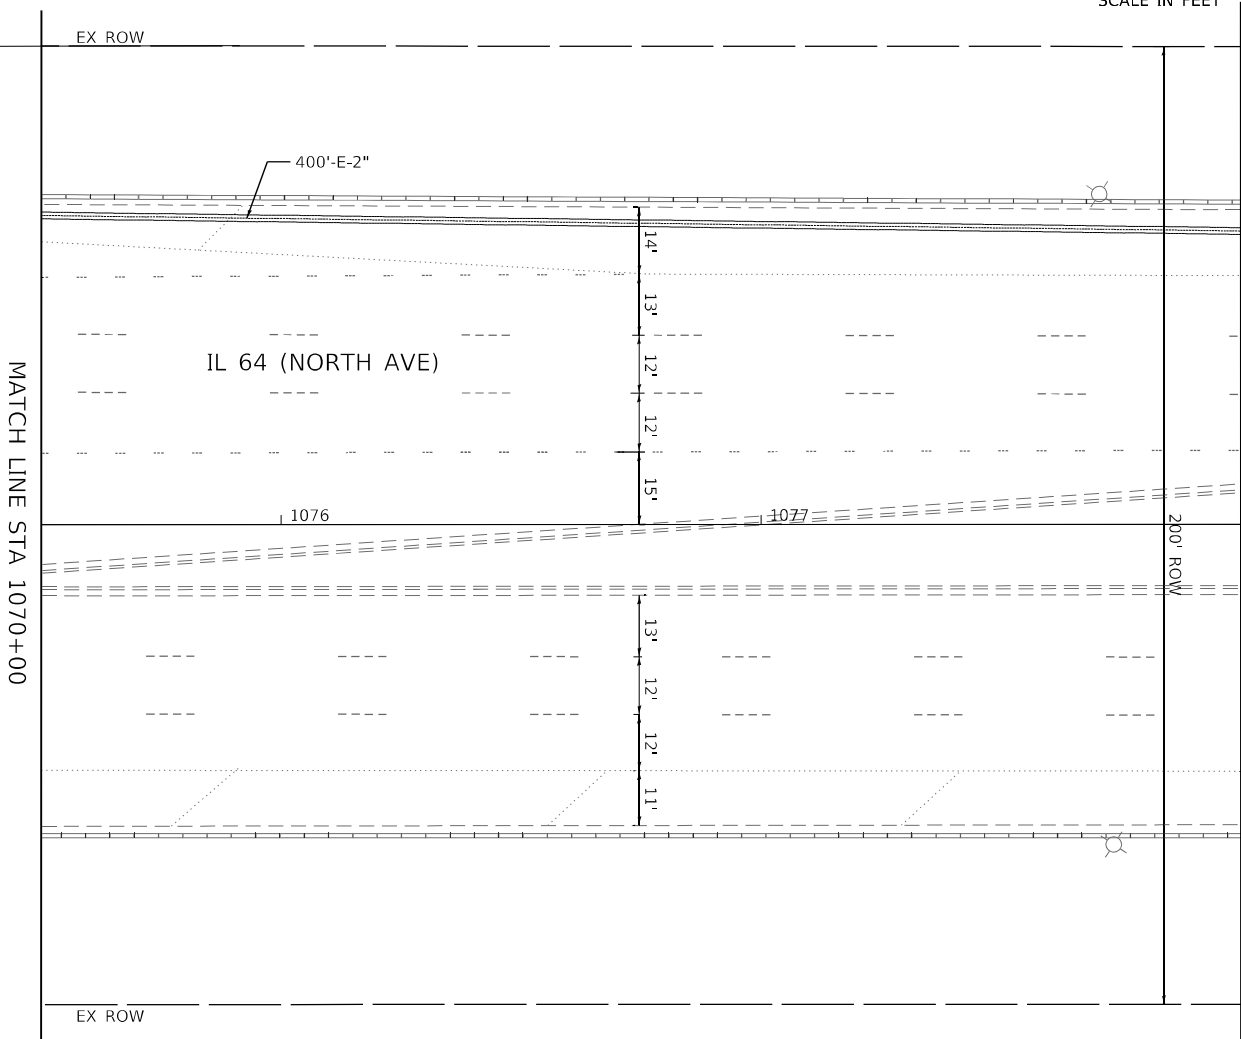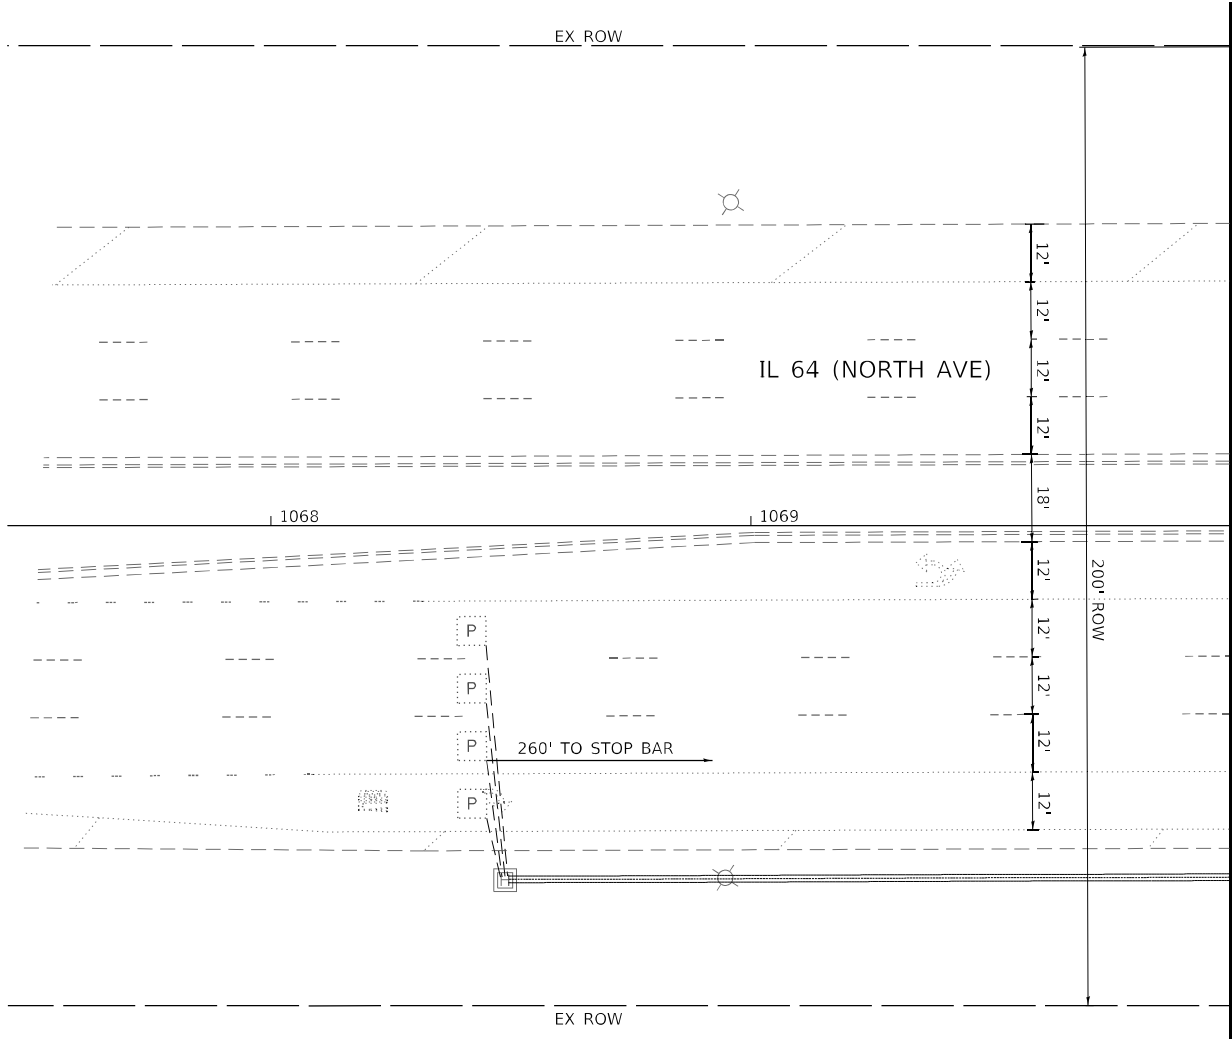

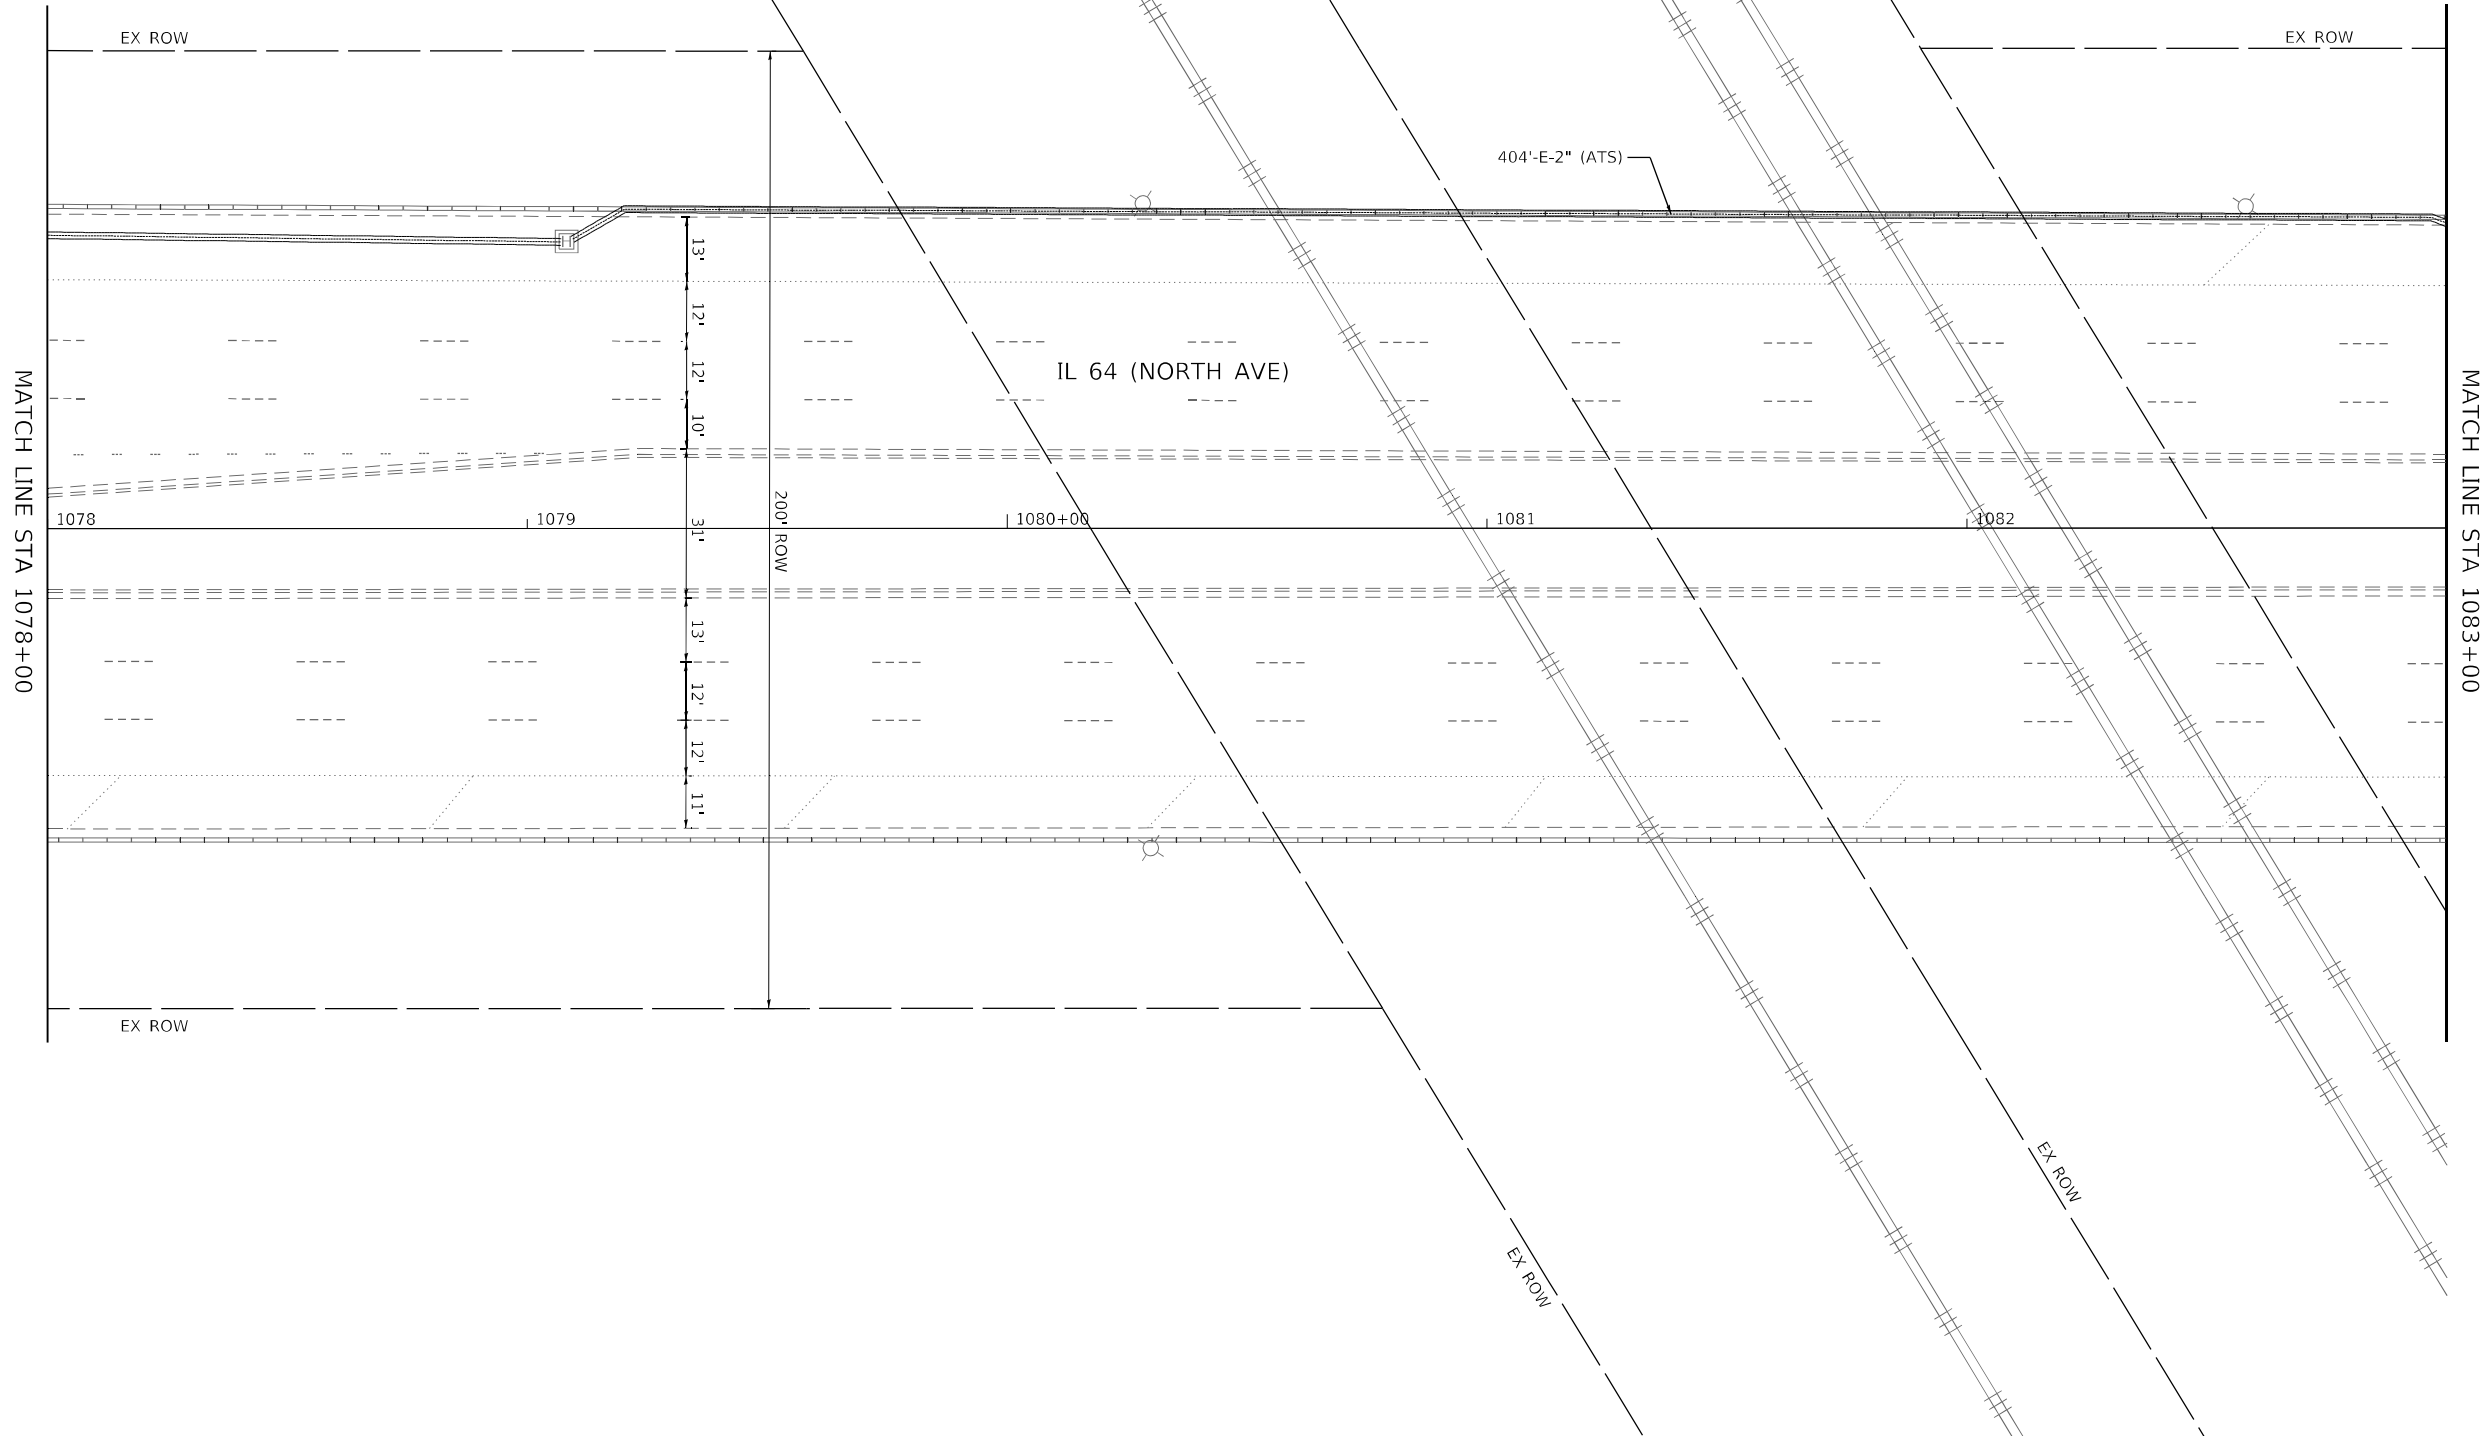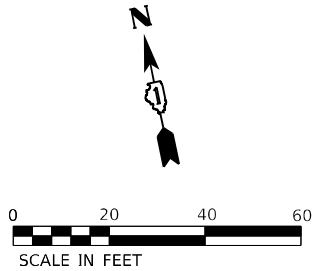

MODEL: Default
FILE: h:\mhc\proj\h-pw-bentley.com\h-pw-d1\Documents\01 Active Projects\MW\CHS-16895\100 - IL 64\Phase II\2 Design\CAD\Plan_Sheets\Signal\West_Corridor_Signal\010817-1-14-14-ts-19_KIM.dgn

Kimley»Horn
© 2021 KIMLEY-HORN AND ASSOCIATES, INC.
4001 WHITE OAK ROAD, SUITE 600
WARREN, ILL. 60555
PHONE: 815.477.4555
WWW.KIMLEY-HORN.COM

USER NAME =	DESIGNED -	REVISED -
	DRAWN -	REVISED -
PLOT SCALE =	CHECKED -	REVISED -
PLOT DATE =	DATE -	REVISED -



STATE OF ILLINOIS
DEPARTMENT OF TRANSPORTATION

TRAFFIC SIGNAL MODERNIZATION PLAN
IL 64 (NORTH AVE) AND POWIS RD

SCALE: 1" = 20' SHEET OF SHEETS STA. TO STA.


F.A.P. RTE.	SECTION	COUNTY	TOTAL SHEETS	SHEET NO.
307	2020-263-SUR, SW&TS	DUPAGE	529	122
CONTRACT NO. 62N33				
ILLINOIS FED. AID PROJECT				

TS 12070
IDOT TACTICS
FORMER EAGLE 2M

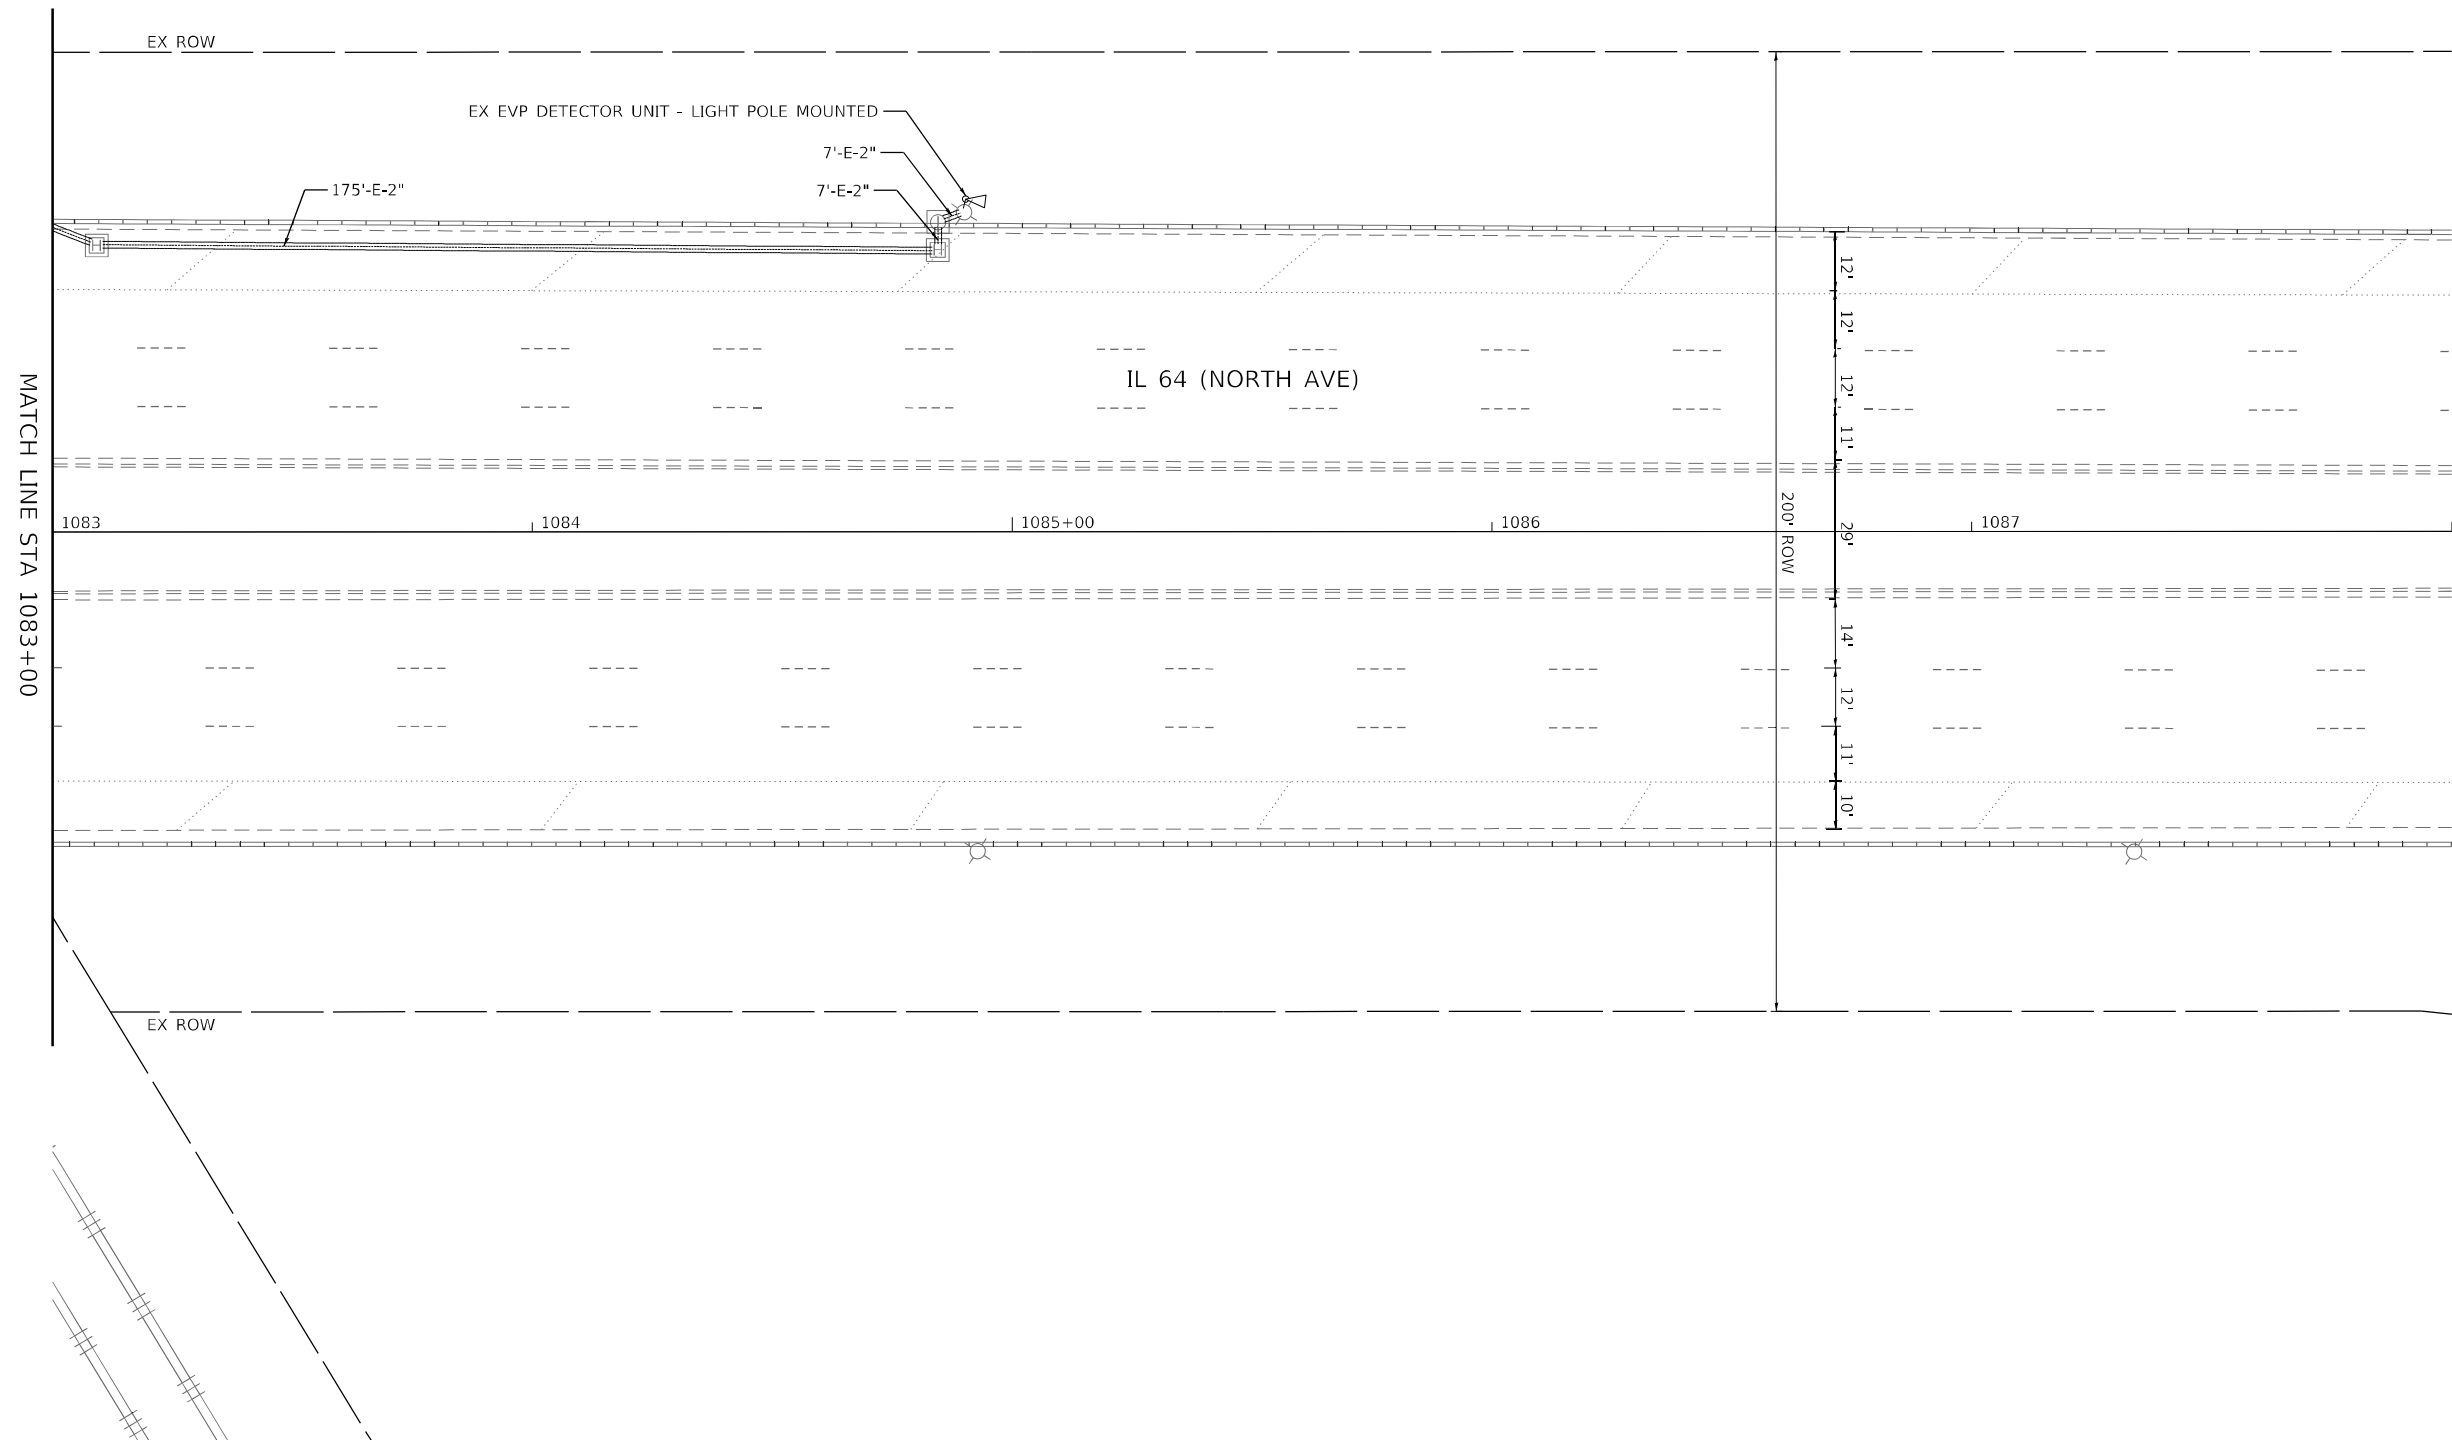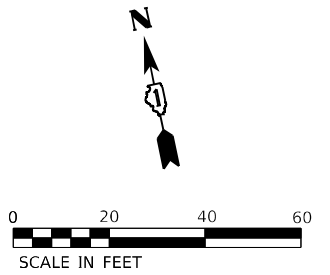


TS 12070
IDOT TACTICS
FORMER EAGLE 2M

EXISTING AND PROPOSED CONTROLLER SEQUENCE

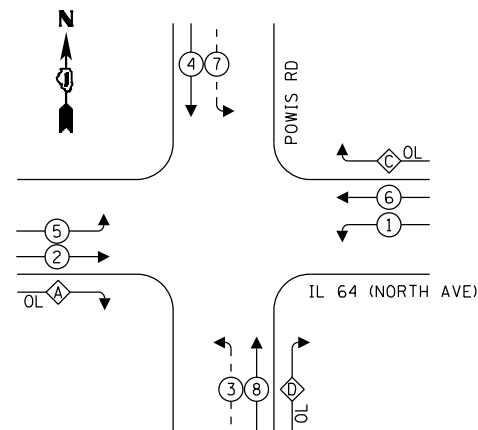


LEGEND:

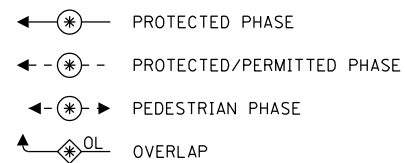

OVERLAP LETTER		PERMISSIVE PHASE		PROTECTED PHASE
A	=	2	+	3
C	=	6	+	7
D	=	8	+	1

EXISTING AND PROPOSED EMERGENCY VEHICLE PREEMPTION SEQUENCE

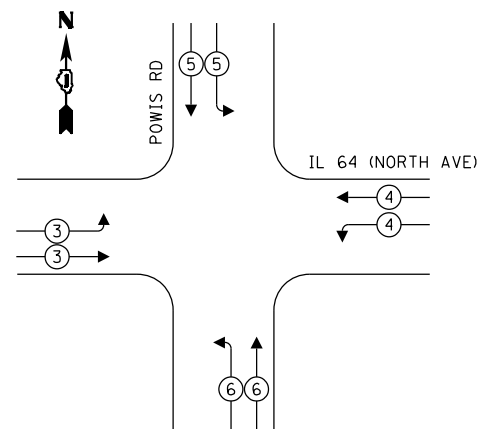

TRAFFIC SIGNAL ELECTRICAL SERVICE REQUIREMENTS


TYPE	QUANTITY	UNIT WATTAGE	TOTAL WATTAGE
SIGNAL HEAD 1 OR 3-SECTION	17	11	187
4-SECTION	-	14	-
5-SECTION	6	13	78
PROGRAMMABLE 3-SECTION	-	22	-
4-SECTION	-	32	-
5-SECTION	-	28	-
PEDESTRIAN SIGNAL	-	15	-
CONTROLLER	1	150	150
MASTER CONTROLLER	-	100	-
UPS	1	25	25
DETECTION VIDEO	2	20	40
BLANK-OUT SIGN	-	25	-
NETWORK SWITCH LAYER II OR III	1	35	35
CELLULAR MODEM	-	15	-
PTZ	1	75	75
TOTAL UPS SIZING			590
UPS CHARGING	1	225	225
BATTERY HEATER MAT	1	180	180
CABINET HEATER	1	200	200
FLASHER	-	15	-
LED STREET NAME SIGN	-	120	-
LUMINAIRE	-	240	-
TOTAL SERVICE WIRE SIZING			1195

ENERGY COSTS TO:
CITY OF WEST CHICAGO
475 MAIN ST
WEST CHICAGO, IL 60185

ENERGY SUPPLY: COMPANY: COMED
PHONE: (866) 639-3532
ACCOUNT NUMBER: 73470-49055

LEGEND:

L = LED LAMP MODULE REPLACEMENT
* = ROADWAY LIGHTING CABLE

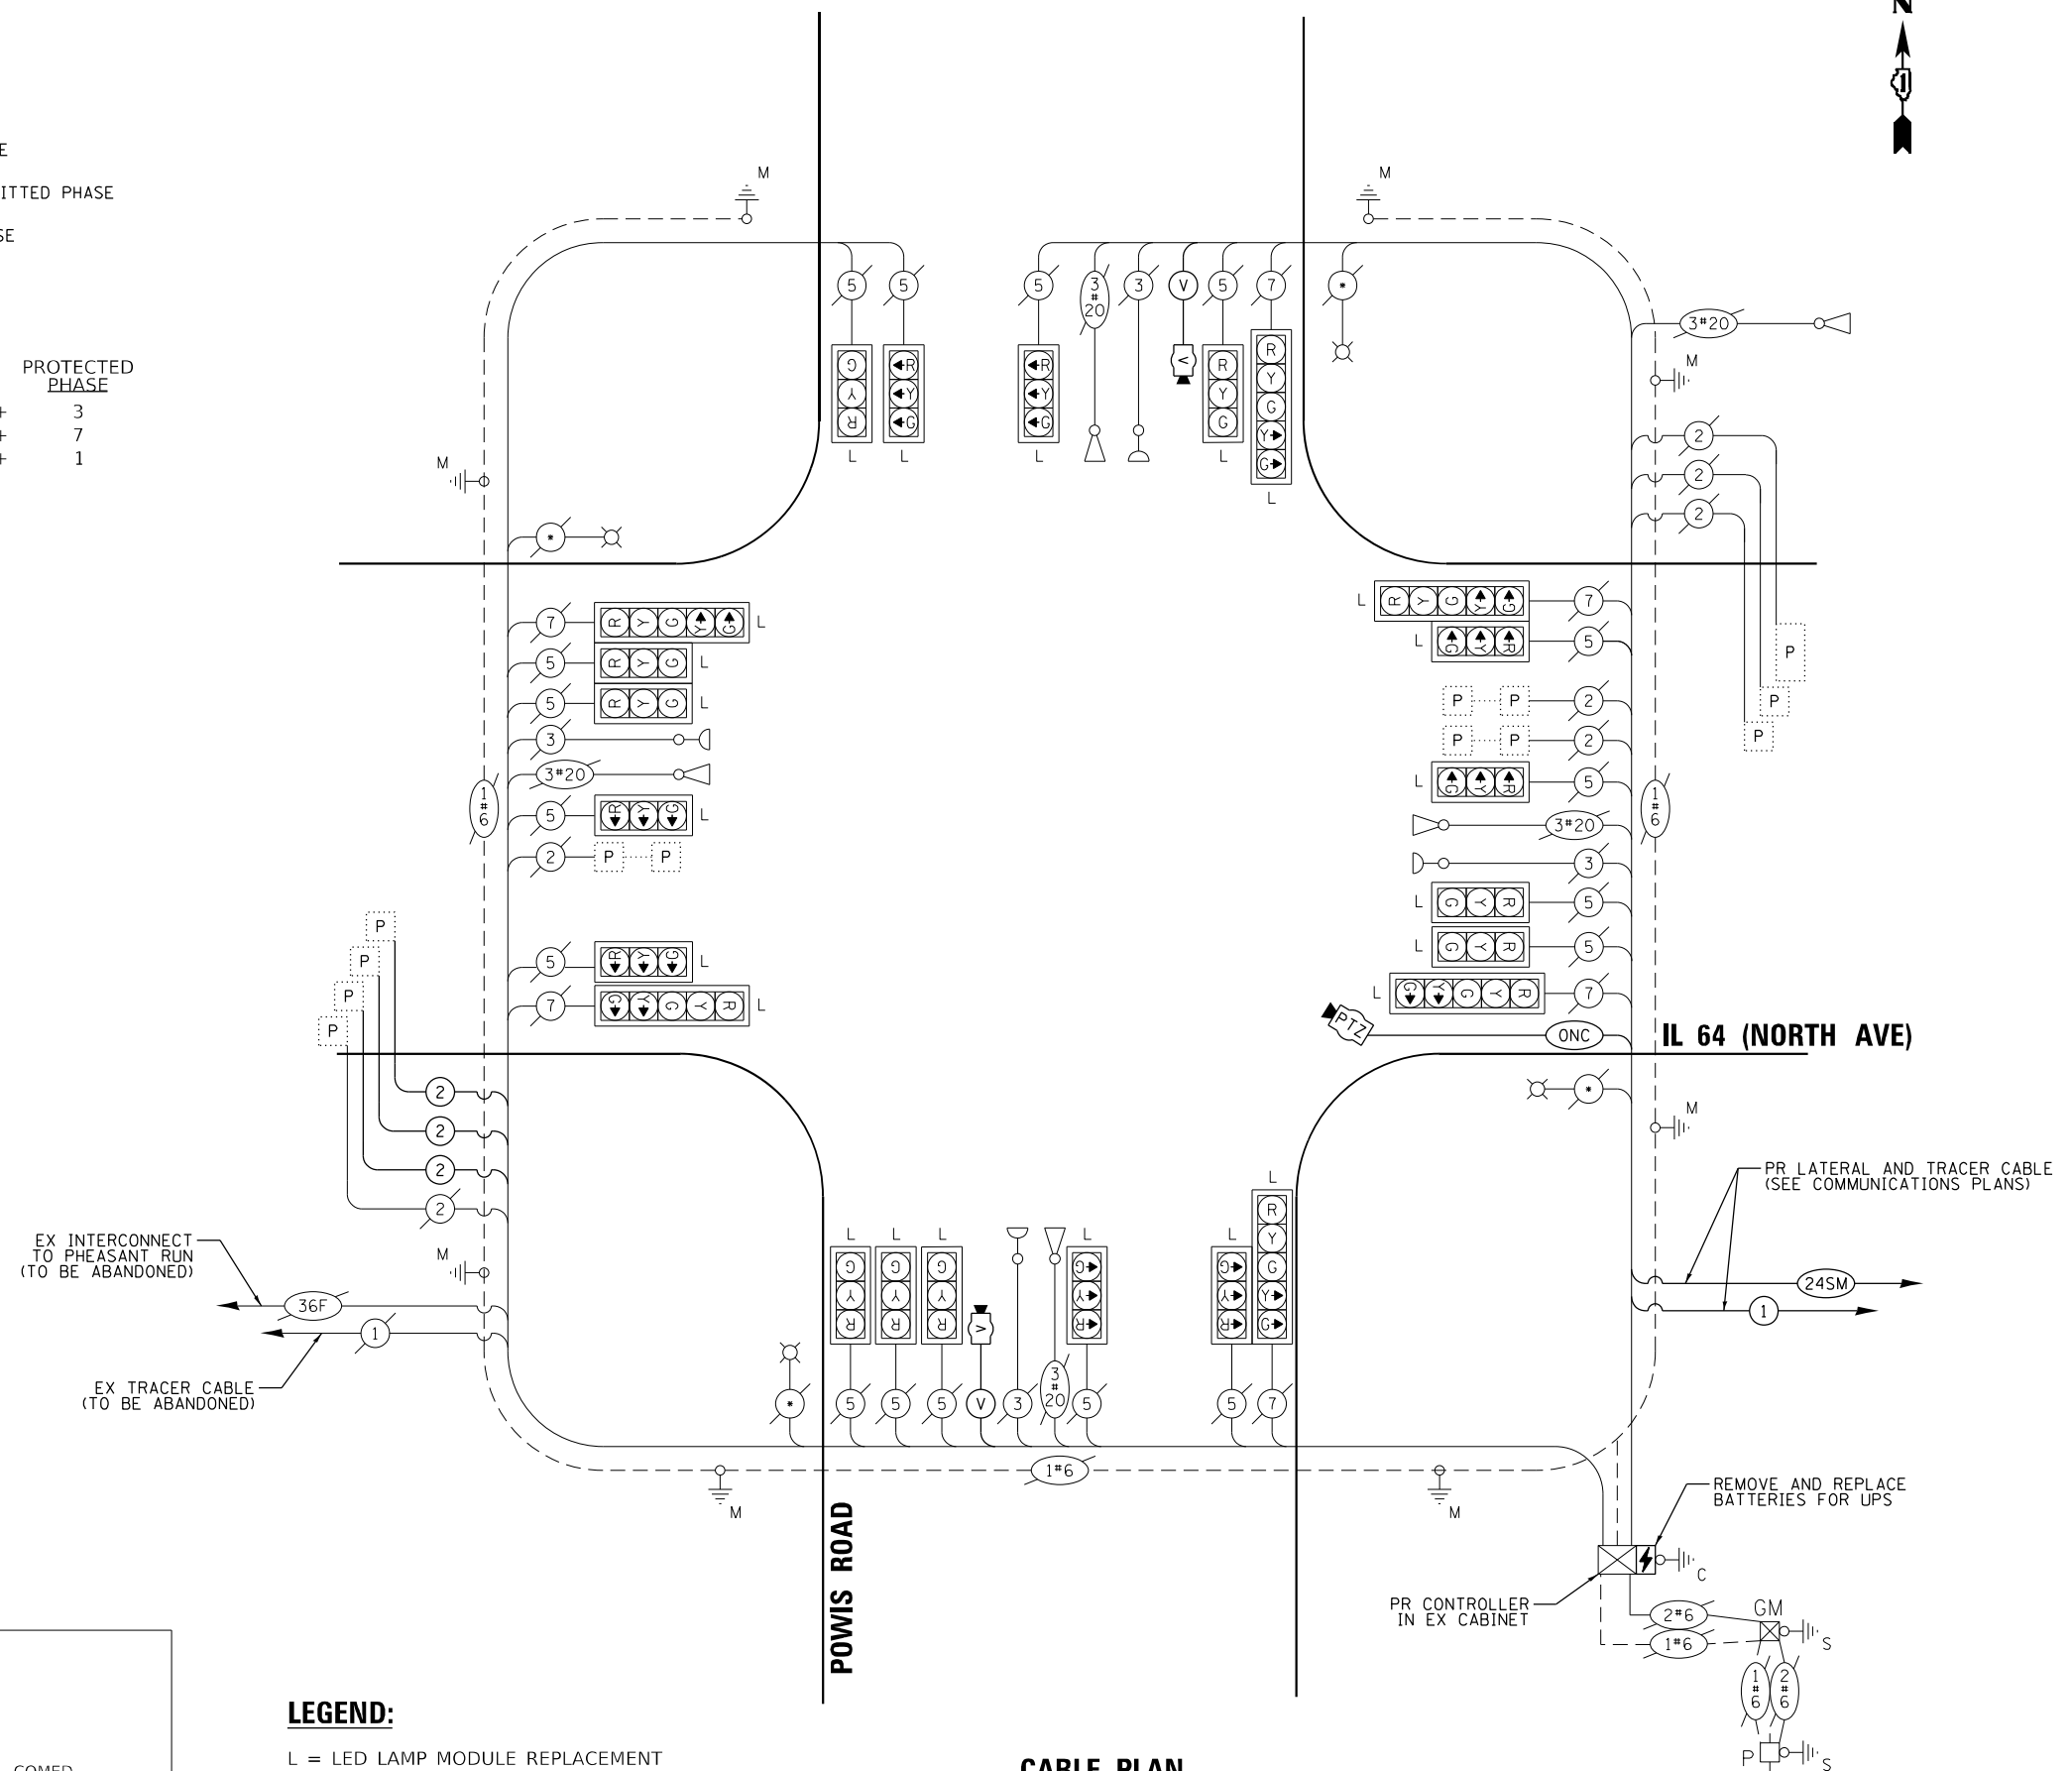

CABLE PLAN

(NOT TO SCALE)

TS 12070
IDOT TACTICS
FORMER EAGLE 2M

**CABLE PLAN, PHASE DESIGNATION DIAGRAM, AND
EMERGENCY VEHICLE PREEMPTION SEQUENCE
IL 64 (NORTH AVE) AND POWIS RD**

SCALE: N.T.S.	SHEET	OF	SHEETS	STA.	TO STA.
---------------	-------	----	--------	------	---------

F.A.P. RTE.	SECTION	COUNTY	TOTAL SHEETS	SHEET NO.
307	2020-263-SUR,SW&TS	DUPAGE	529	124
		CONTRACT NO. 62N33		
		ILLINOIS	FED. AID PROJECT	

**STATE OF ILLINOIS
DEPARTMENT OF TRANSPORTATION**

Kimley»Horn

© 2023 KIMLEY-HORN AND ASSOCIATES, INC.
4201 WINFIELD ROAD, SUITE 600
WARREN, ILL. 60555
PHONE: 630-487-6550
WWW.KIMLEY-HORN.COM

USER NAME	=	
PLOT SCALE	=	
PLOT DATE	=	

DESIGNED -	REVISED -
DRAWN -	REVISED -
CHECKED -	REVISED -
DATE -	REVISED -

MODEL: Default
FILE NAME: pw:\kh-pw\bentlev.com\kh-pw-01\Documents\01 Active Projects\MW-CHS-16895100 - IL 64\Phase II\2 Design\CAD\Plan Sheets\Signals\West Corridor Signals\ID108121-sht-ts-2 1_KHA.dgn



1. THE EXISTING TRAFFIC SIGNAL EQUIPMENT SHALL NOT BE REMOVED UNTIL THE PROPOSED TRAFFIC SIGNAL EQUIPMENT IS FULLY OPERATIONAL OR AS DIRECTED BY THE ENGINEER.
2. ALL EXISTING TRAFFIC SIGNAL CABLE NO LONGER REQUIRED SHALL BE REMOVED.
3. THE EXISTING SERVICE METER SHALL BE RELOCATED TO THE PROPOSED GROUND MOUNTED SERVICE CABINET. THE EXISTING SERVICE METER HOUSING SHALL REMAIN AT THE EXISTING TRAFFIC SIGNAL CONTROLLER CABINET AND ALL HOLES BETWEEN THE EXISTING HOUSING AND THE EXISTING CABINET SHALL BE PLUGGED. THIS WORK SHALL BE INCLUDED IN THE PAY ITEM "SERVICE INSTALLATION, GROUND MOUNTED, METERED".

THE FOLLOWING ITEMS SHALL BE REMOVED BY THE CONTRACTOR AND SHALL BE DISPOSED OF BY THEM OUTSIDE THE RIGHT-OF-WAY AT THEIR EXPENSE. THE SALVAGE VALUE OF THE REMOVED EQUIPMENT SHALL BE REFLECTED IN THE CONTRACT BID PRICE.

- THE FOLLOWING ITEMS SHALL BE REMOVED BY THE CONTRACTOR, SHALL REMAIN THE PROPERTY OF THE ILLINOIS DEPARTMENT OF TRANSPORTATION, AND SHALL BE DELIVERED BY THE CONTRACTOR TO IDOT'S TRAFFIC SIGNAL MAINTENANCE CONTRACTOR'S MAIN FACILITY.

-
- A north arrow pointing upwards and a scale bar in feet. The scale bar is marked from 0 to 60 feet, with a 10-foot segment shaded.



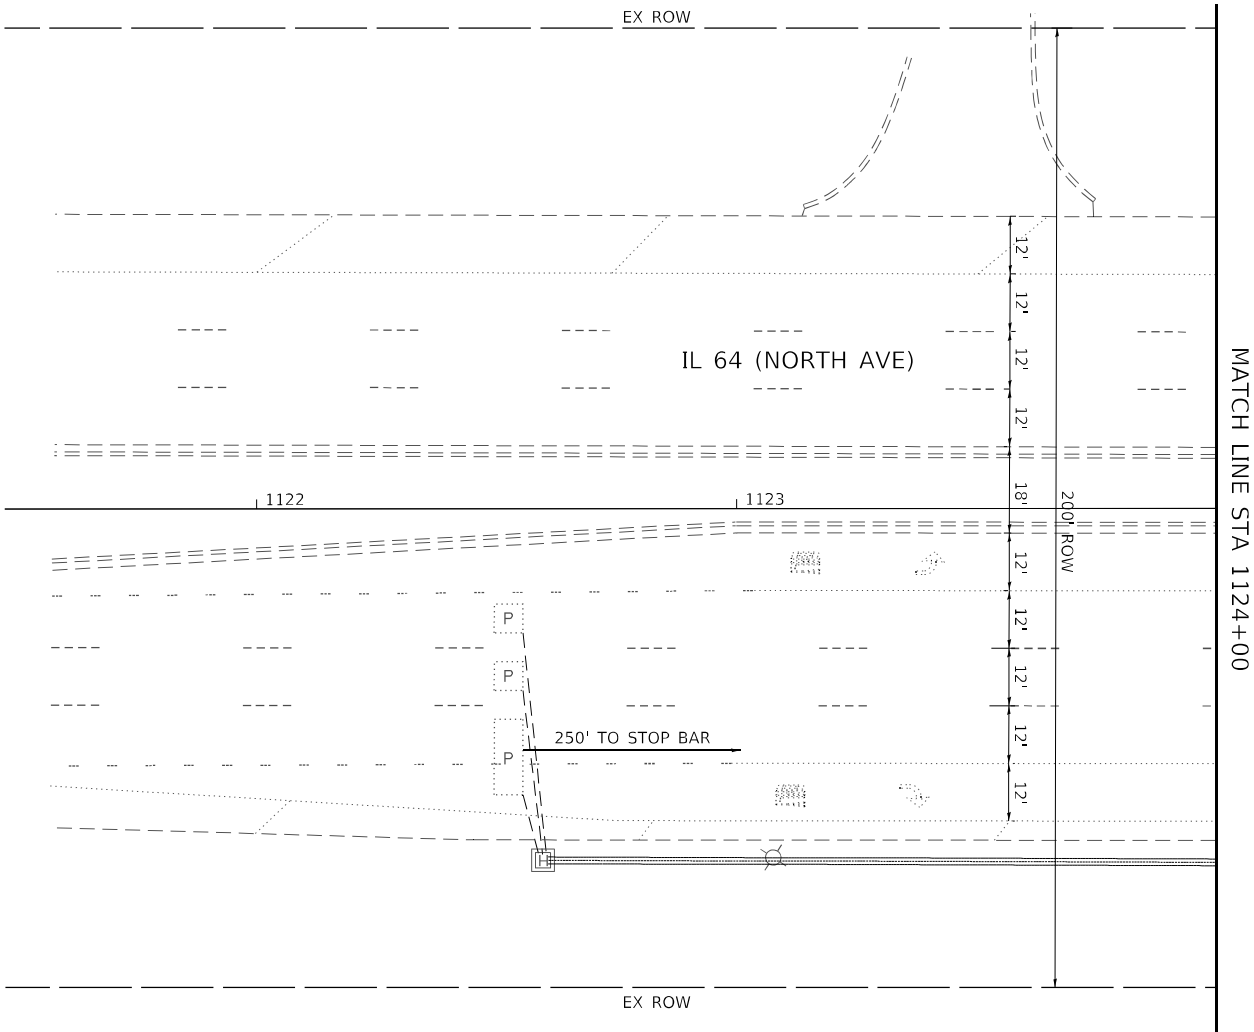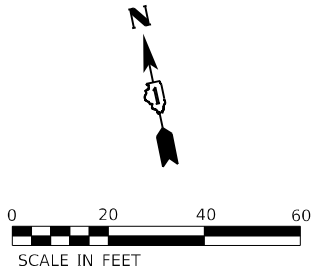

MODEL: Default
FILE NAME: p:\bentley.com\khp\p4\1\Documents\01 Active Projects\MW\CHS-168950\00 - IL 64\Phase 1\2 Design\CAD\Plan_Sheets\Signal\West Corridor_Signal\01-14-14-ts-24_KH.dgn



USER NAME =	DESIGNED -	REVISED -
	DRAWN -	REVISED -
PLOT SCALE =	CHECKED -	REVISED -
PLOT DATE =	DATE -	REVISED -

STATE OF ILLINOIS
DEPARTMENT OF TRANSPORTATION

TRAFFIC SIGNAL EQUIPMENT REMOVAL PLAN			
IL 64 (NORTH AVE) AND ATLANTIC DR			
SCALE: 1" = 20'	SHEET	OF	SHEETS
STA.		TO STA.	

F.A.P. RTE.	SECTION	COUNTY	TOTAL SHEETS	SHEET NO.
307	2020-263-SUR,SW&TS	DUPAGE	529	127
CONTRACT NO. 62N33				
ILLINOIS		FED. AID PROJECT		



TS 12373
IDOT TACTICS
FORMER EAGLE 5A

A
LEFT ON
GREEN
ARROW
ONLY

R10-5
30" X 36"
(4 REQUIRED)

NOTES

1. ALL PROPOSED TRAFFIC SIGNAL CABLE SHALL BE ROUTED THROUGH THE PROPOSED CONDUIT.
2. A SEPARATE LEAD-IN CABLE SHALL BE INSTALLED FOR THE DETECTOR LOOPS ON IL 64 (NORTH AVE).
3. PROPOSED CONDUIT SHALL BE SPLICED TO THE EXISTING CONDUIT AND EXTENDED VERTICALLY THROUGH THE PROPOSED FOUNDATION AT THE GROUND MOUNTED SERVICE LOCATION. THE COST OF THE CONDUIT SHALL BE INCLUDED IN THE COST OF "CONCRETE FOUNDATION, TYPE A".

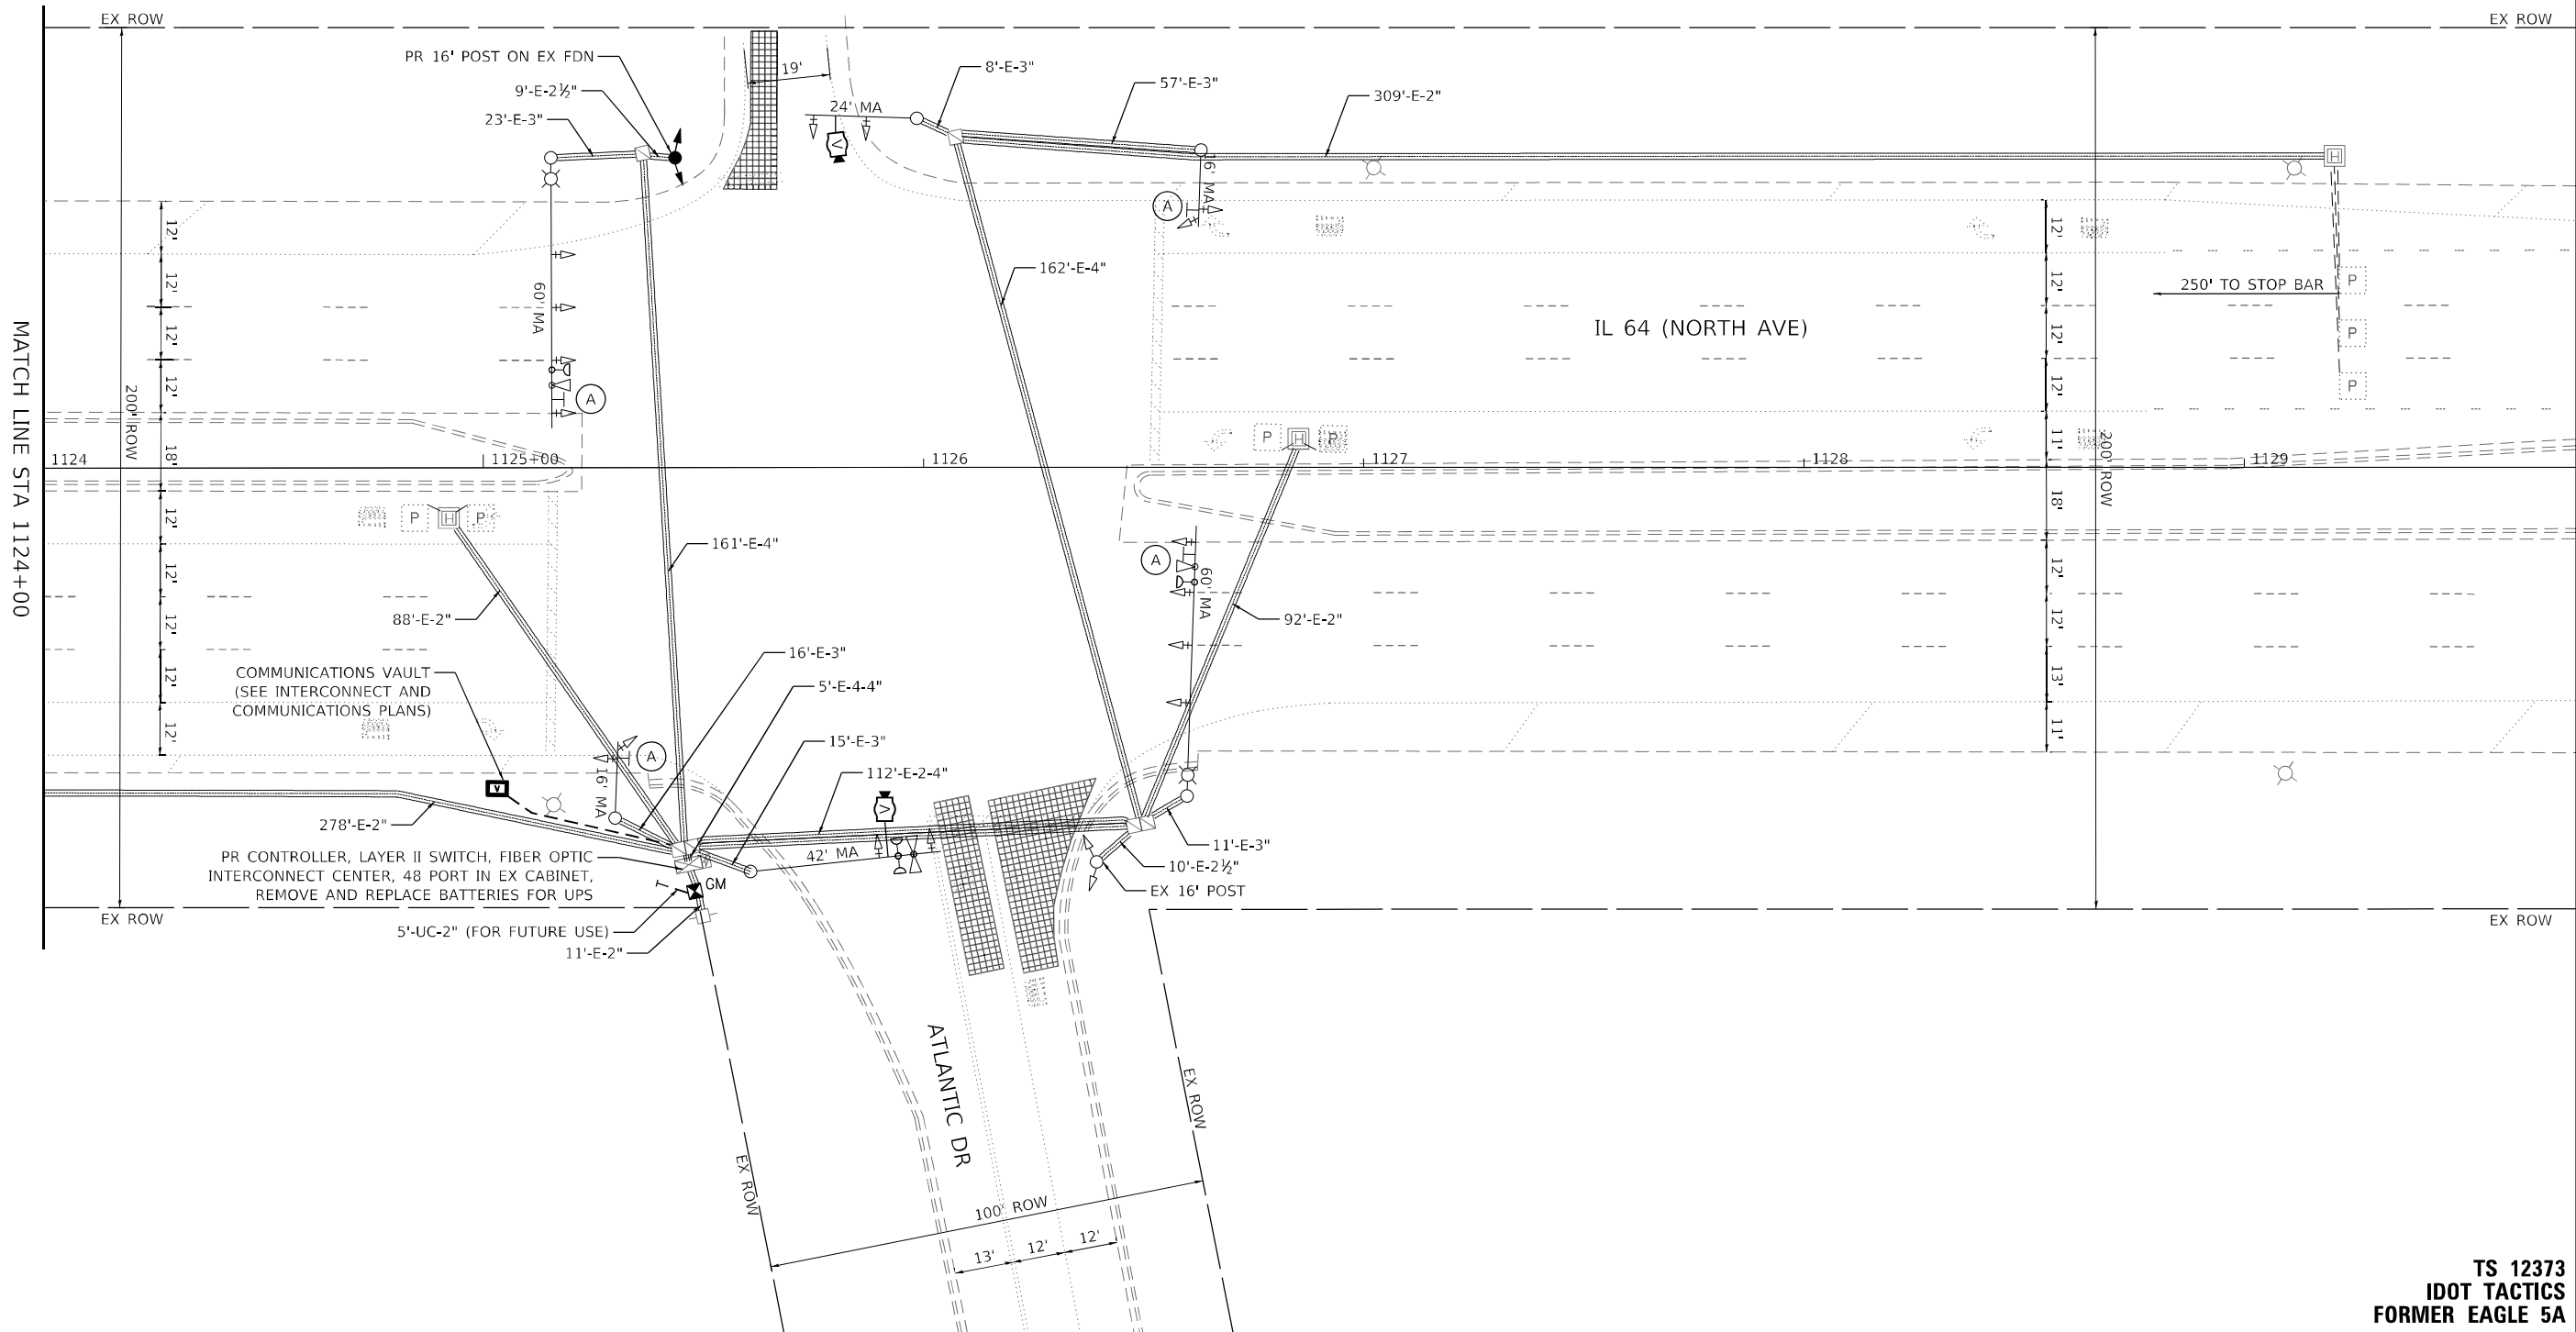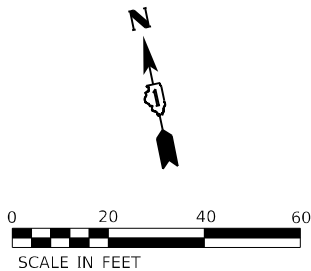

TS 12373
IDOT TACTICS
FORMER EAGLE 5A

Kimley»Horn

© 2023 KIMLEY-HORN AND ASSOCIATES, INC.
4001 WILSON ROAD, SUITE 600
WARREN, ILL. 60555
PHONE: (847) 455-4555
WWW.KIMLEY-HORN.COM



USER NAME =	DESIGNED -	REVISED -
	DRAWN -	REVISED -
PLOT SCALE =	CHECKED -	REVISED -
PLOT DATE =	DATE -	REVISED -

STATE OF ILLINOIS
DEPARTMENT OF TRANSPORTATION

TRAFFIC SIGNAL MODERNIZATION PLAN
IL 64 (NORTH AVE) AND ATLANTIC DR

SCALE: 1" = 20' SHEET OF SHEETS STA. TO STA.

F.A.P. RTE.	SECTION	COUNTY	TOTAL SHEETS	SHEET NO.
307	2020-263-SUR, SW&TS	DUPAGE	529	128
CONTRACT NO. 62N33				
ILLINOIS FED. AID PROJECT				

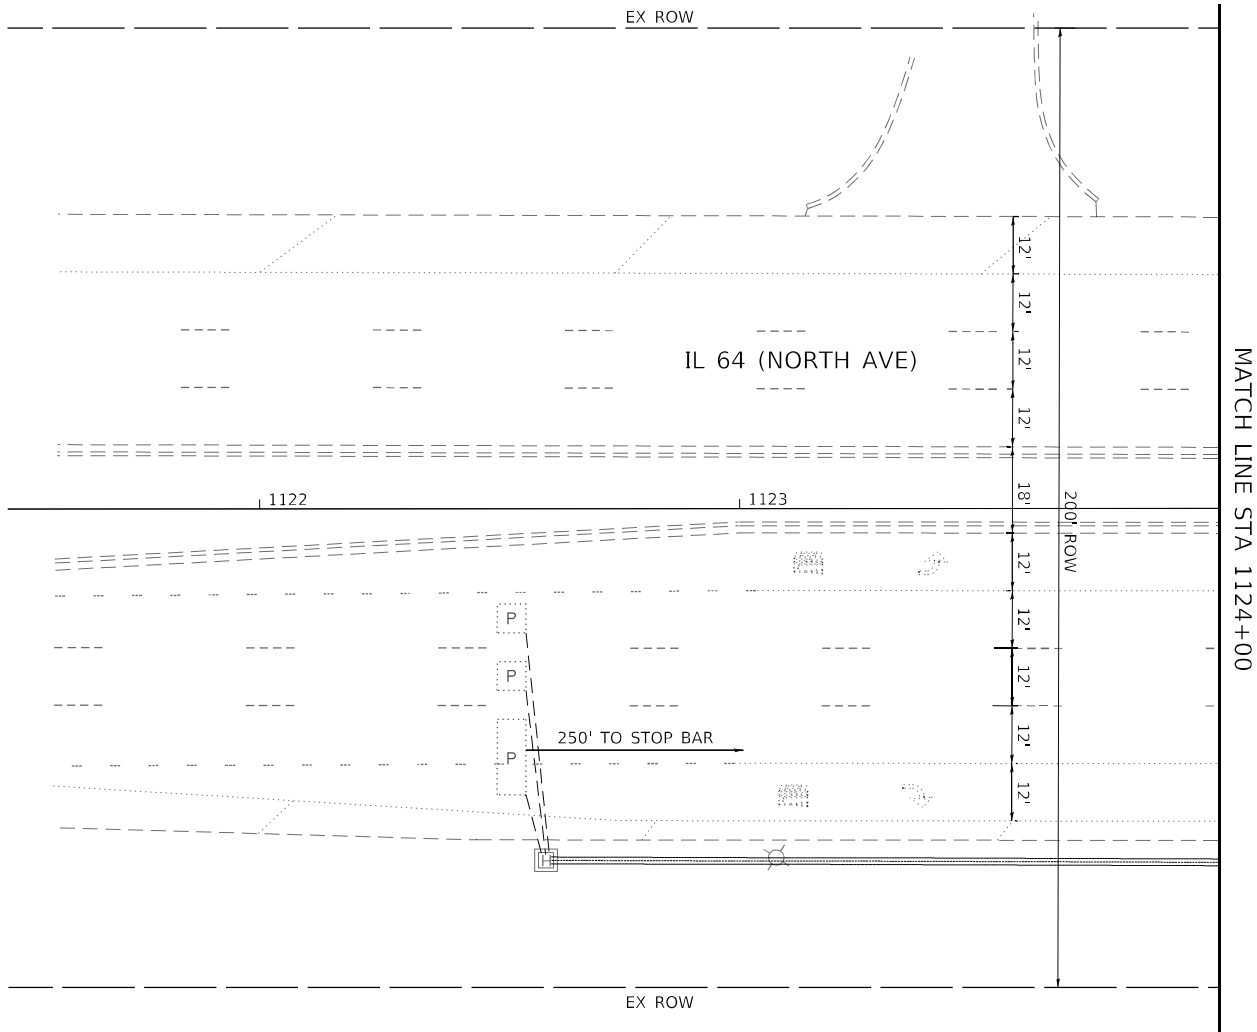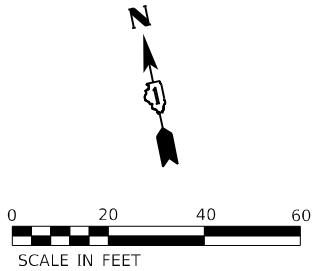

MODEL: Default
FILE NAME: p:\bentley.com\khp\p4\11\Documents\01 Active Projects\IMW\CHS-168950\00 - IL 64\Phase 1\2 Design\CAD\Plan Streets\Signal\West Corridor_Signal\010817-14\ts-36_KIM.dgn



USER NAME	=	DESIGNED	-
		DRAWN	-
PLOT SCALE	=	CHECKED	-
PLOT DATE	=	DATE	-
		REVISED	-
		REVISED	-
		REVISED	-
		REVISED	-

STATE OF ILLINOIS
DEPARTMENT OF TRANSPORTATION

TRAFFIC SIGNAL MODERNIZATION PLAN
IL 64 (NORTH AVE) AND ATLANTIC DR

SCALE: 1" = 20' SHEET OF SHEETS STA. TO STA.

F.A.P. RTE.	SECTION	COUNTY	TOTAL SHEETS	SHEET NO.
307	2020-263-SUR,SW&TS	DUPAGE	529	129
CONTRACT NO. 62N33				
		ILLINOIS	FED. AID PROJECT	

TS 12373
IDOT TACTICS
FORMER EAGLE 5A

The diagram illustrates a four-way intersection. The vertical road is labeled "ATLANTIC DR" and the horizontal road is labeled "IL 64 (NORTH AVE)".

- Northbound (Atlantic Dr):** Features a traffic light with a red circle and the number "4". A north arrow is located at the top left of the diagram.
- Southbound (Atlantic Dr):** Features a traffic light with a red circle and the number "8". A diamond-shaped advance warning sign with the number "10" is positioned before the intersection.
- Eastbound (IL 64):** Features a traffic light with a red circle and the number "1".
- Westbound (IL 64):** Features a traffic light with a red circle and the number "6".
- Southbound Left Lane (Atlantic Dr):** Features a traffic light with a red circle and the number "2".
- Southbound Through/Right Lane (Atlantic Dr):** Features a traffic light with a red circle and the number "5".

 PROTECTED PHASE
 PROTECTED/PERMITTED PHASE
 PEDESTRIAN PHASE
 OVERLAP

OVERLAP <u>LETTER</u>		PERMISSIVE <u>PHASE</u>		PROTECTED <u>PHASE</u>
D	=	8	+	1

TYPE	QUANTITY	UNIT WATTAGE	TOTAL WATTAGE
SIGNAL HEAD 1 OR 3-SECTION	18	11	198
4-SECTION	-	14	-
5-SECTION	2	13	26
PROGRAMMABLE 3-SECTION	-	22	-
4-SECTION	-	32	-
5-SECTION	-	28	-
PEDESTRIAN SIGNAL	-	15	-
CONTROLLER	1	150	150
MASTER CONTROLLER	-	100	-
UPS	1	25	25
DETECTION VIDEO	2	20	40
BLANK-OUT SIGN	-	25	-
NETWORK SWITCH LAYER II OR III	1	35	35
CELLULAR MODEM	-	15	-
PTZ	-	75	-
TOTAL UPS SIZING			474
UPS CHARGING	1	225	225
BATTERY HEATER MAT	1	180	180
CABINET HEATER	1	200	200
FLASHER	-	15	-
LED STREET NAME SIGN	-	120	-
LUMINAIRE	-	240	-


ENERGY COSTS TO:
CITY OF WEST CHICAGO
475 MAIN ST
WEST CHICAGO, IL 60185

ENERGY SUPPLY: COMPANY: COMED
PHONE: (866) 639-3532
ACCOUNT NUMBER: 73470-49055

LEGEND:

L = LED LAMP MODULE REPLACEMENT

* = ROADWAY LIGHTING CABLE

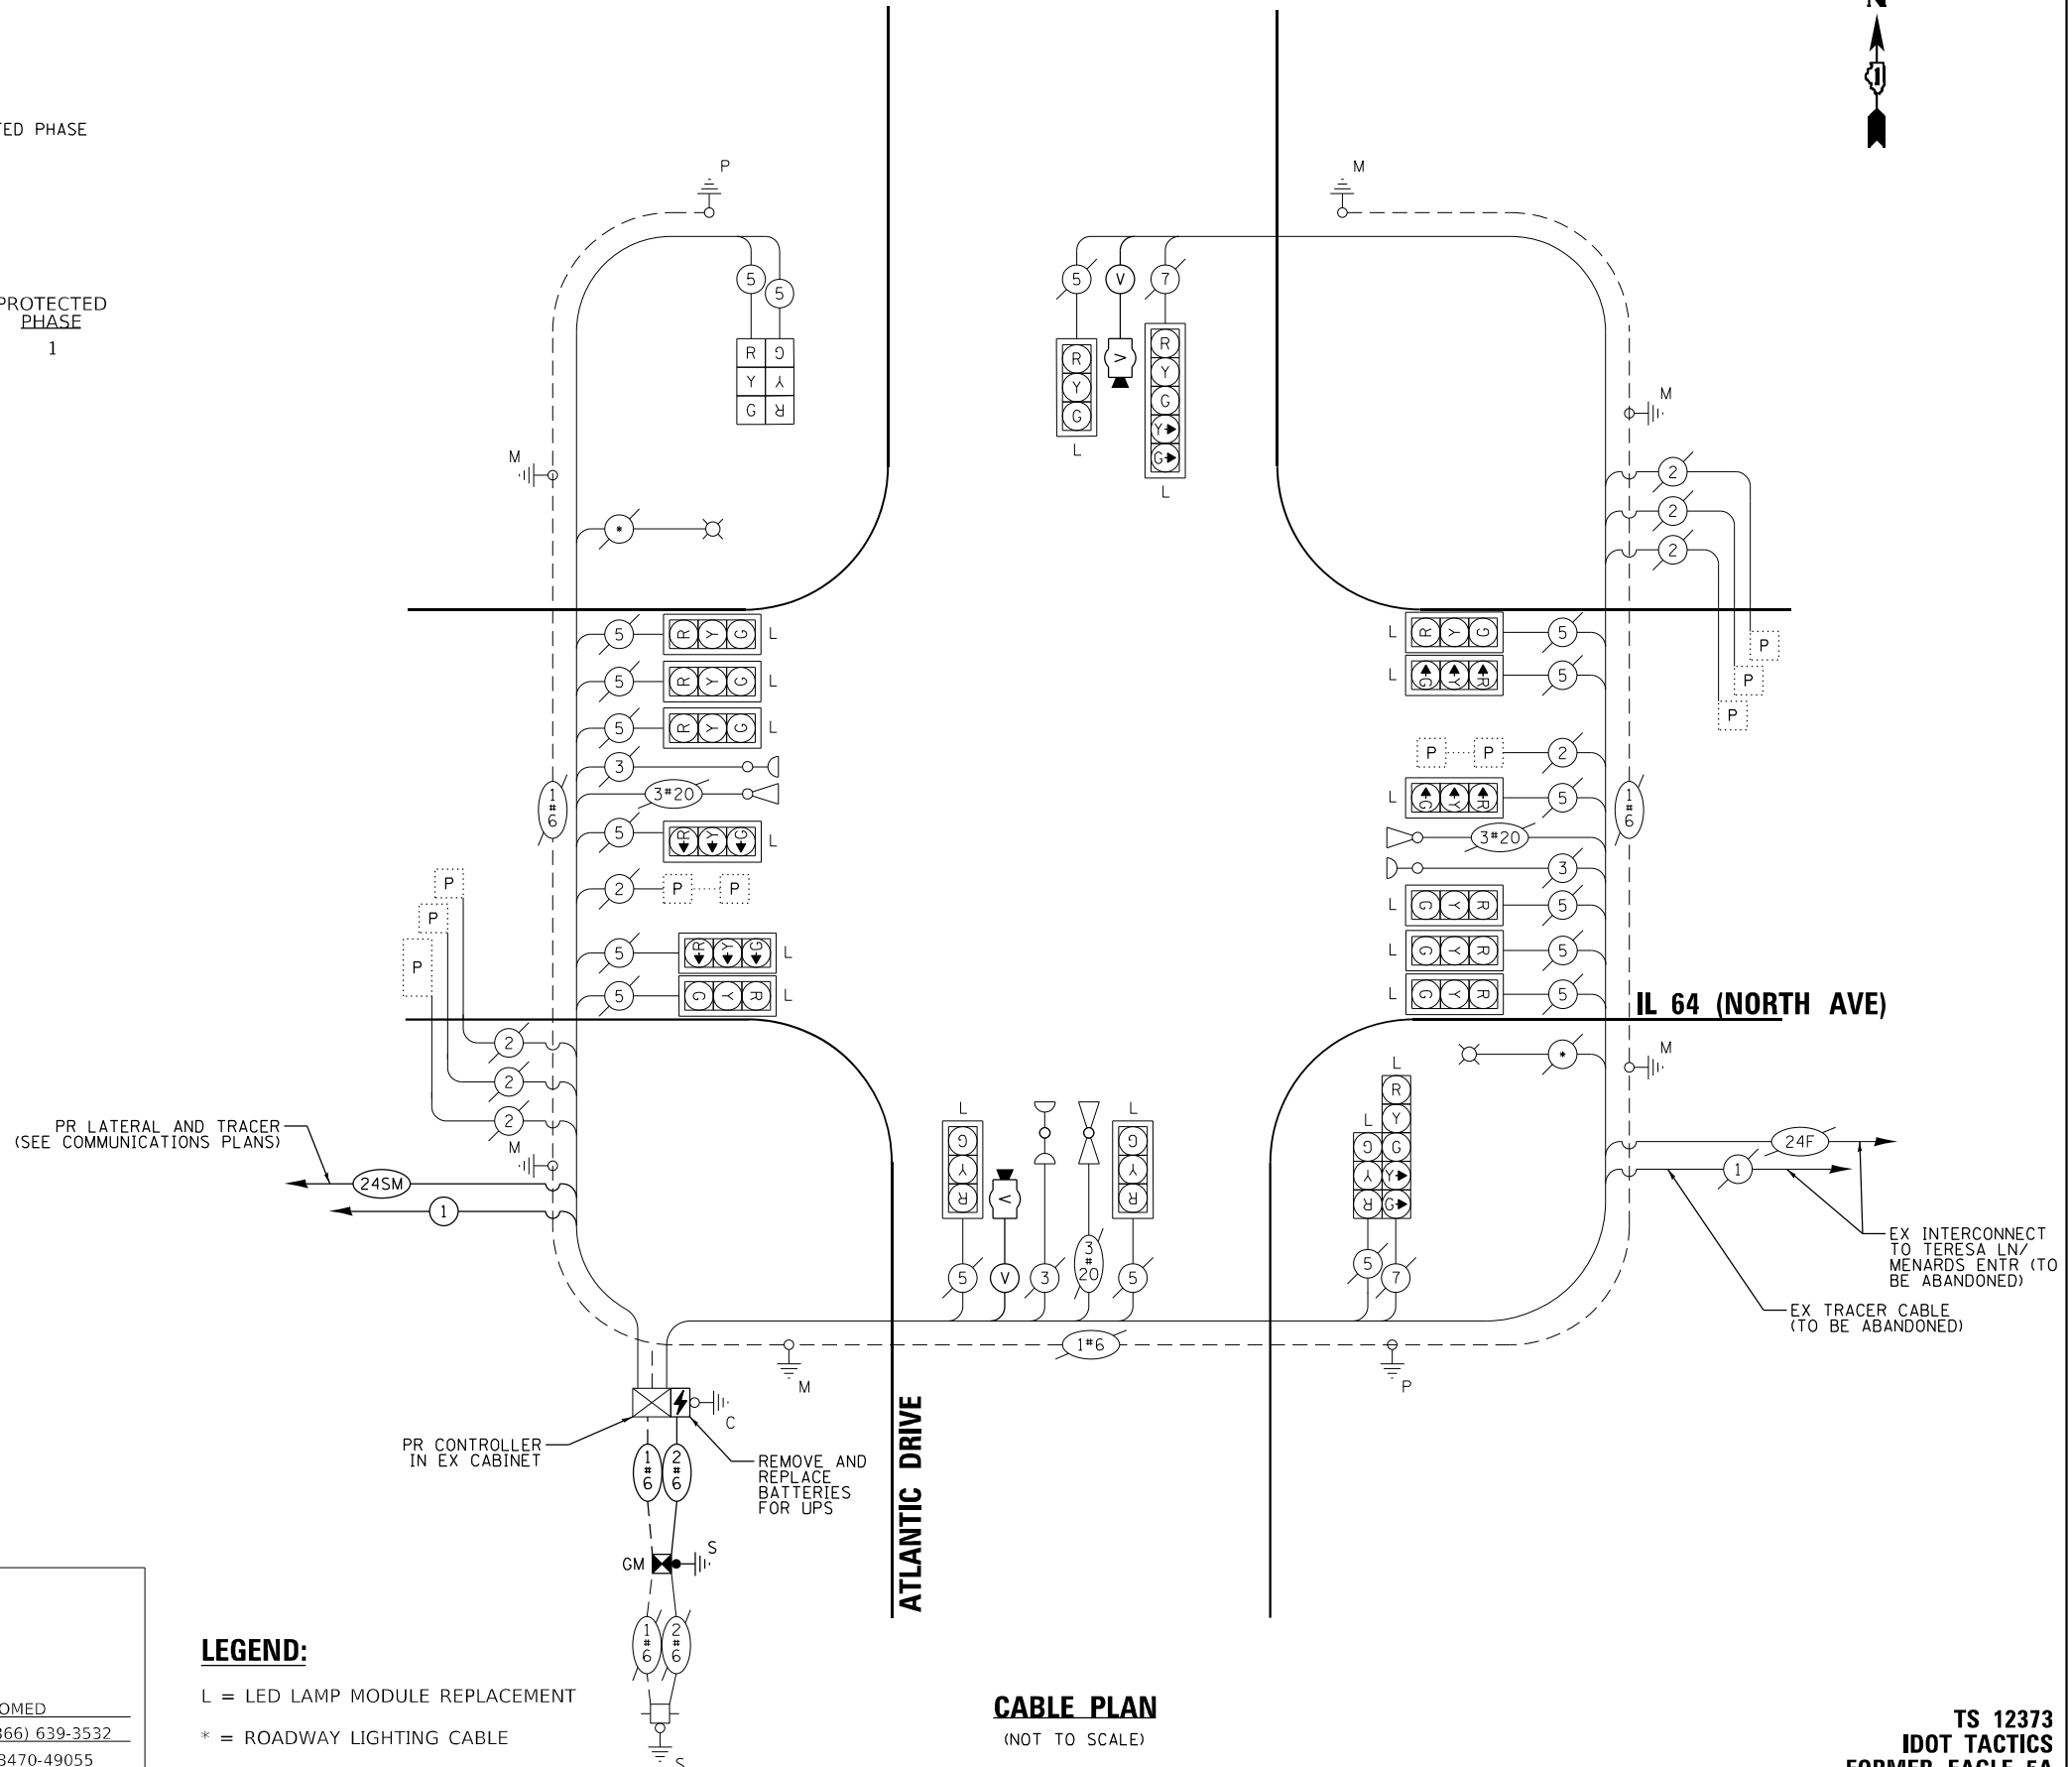

TS 12373
IDOT TACTICS
FORMER EAGLE 5A

SIGN PANEL – TYPE 2

ALL DIMENSIONS ARE IN INCHES UNLESS OTHERWISE NOTED



DESIGN SERIES	AREA (SQ FT)	SIGN PANEL TYPE	SHEETING TYPE	QTY. REQUIRED
D	12.5	2	ZZ	2

SCHEDULE OF QUANTITIES

ITEM DESCRIPTION	UNIT	QUANTITY
SIGN PANEL - TYPE 2	SQ FT	25
UNDERGROUND CONDUIT, GALVANIZED STEEL, 2" DIA.	FOOT	5
MAINTENANCE OF EXISTING TRAFFIC SIGNAL INSTALLATION	EACH	1
ELECTRIC CABLE IN CONDUIT, SERVICE, NO. 6 2 C	FOOT	38
ELECTRIC CABLE IN CONDUIT, EQUIPMENT GROUNDING CONDUCTOR, NO. 6 1C	FOOT	38
TRAFFIC SIGNAL POST, GALVANIZED STEEL 16 FT.	EACH	1
CONCRETE FOUNDATION, TYPE A	FOOT	4
SIGNAL HEAD, LED, 1-FACE, 3-SECTION, BRACKET MOUNTED	EACH	2
REMOVE ELECTRIC CABLE FROM CONDUIT	FOOT	38
REMOVE EXISTING TRAFFIC SIGNAL EQUIPMENT	EACH	1
REMOVE EXISTING HANDHOLE	EACH	1
LED LAMP MODULE REPLACEMENT	EACH	58
SERVICE INSTALLATION, GROUND MOUNTED, METERED	EACH	1
LAYER II (DATALINK) SWITCH	EACH	1
TERMINATE FIBER IN CABINET	EACH	12
TACTICS LICENSE EXPANSION	EACH	1
FULL-ACTUATED CONTROLLER IN EXISTING CABINET	EACH	1
REMOVE AND REPLACE BATTERIES FOR UNINTERRUPTABLE POWER SUPPLY, EXTENDED	EACH	1
FIBER OPTIC INTERCONNECT CENTER, 48 PORT	EACH	1
LED SIGNAL FACE, LENS COVER	EACH	20
VIDEO VEHICLE DETECTION SYSTEM, SINGLE APPROACH	EACH	2

TS 12373
IDOT TACTICS
FORMER EAGLE 5A

MODEL: Default
FILE: h:\mhc\proj\hwy-bentley.com\hwy-d\1\documents\01 Active Projects\MWL-CL-5-160950\00 - IL 64\Phase II\2 Design\CAD\Plan Sheets\Sign\InWest Corridor-Sign\BID\081714-IL-Rte-38-K4A.dgn



© 2023 KIMLEY-HORN AND ASSOCIATES, INC.
4001 HWY 10, SUITE 400
WARREN, IL 60555
PHONE: 815.447.4555
WWW.KIMLEY-HORN.COM

USER NAME =	DESIGNED -	REVISED -
	DRAWN -	REVISED -
PLOT SCALE =	CHECKED -	REVISED -
PLOT DATE =	DATE -	REVISED -


STATE OF ILLINOIS
DEPARTMENT OF TRANSPORTATION

SCHEDULE OF QUANTITIES			
IL 64 (NORTH AVE) AND ATLANTIC DR			
SCALE: N.T.S.	SHEET OF SHEETS	STA. TO STA.	

F.A.P. RTE.	SECTION	COUNTY	TOTAL SHEETS	SHEET NO.
307	2020-263-SUR,SW&TS	DUPAGE	529	131
CONTRACT NO. 62N33				
ILLINOIS FED. AID PROJECT				

NOTES

1. THE EXISTING TRAFFIC SIGNAL EQUIPMENT SHALL NOT BE REMOVED UNTIL THE PROPOSED TRAFFIC SIGNAL EQUIPMENT IS FULLY OPERATIONAL OR AS DIRECTED BY THE ENGINEER.
2. ALL EXISTING TRAFFIC SIGNAL CABLE NO LONGER REQUIRED SHALL BE REMOVED.

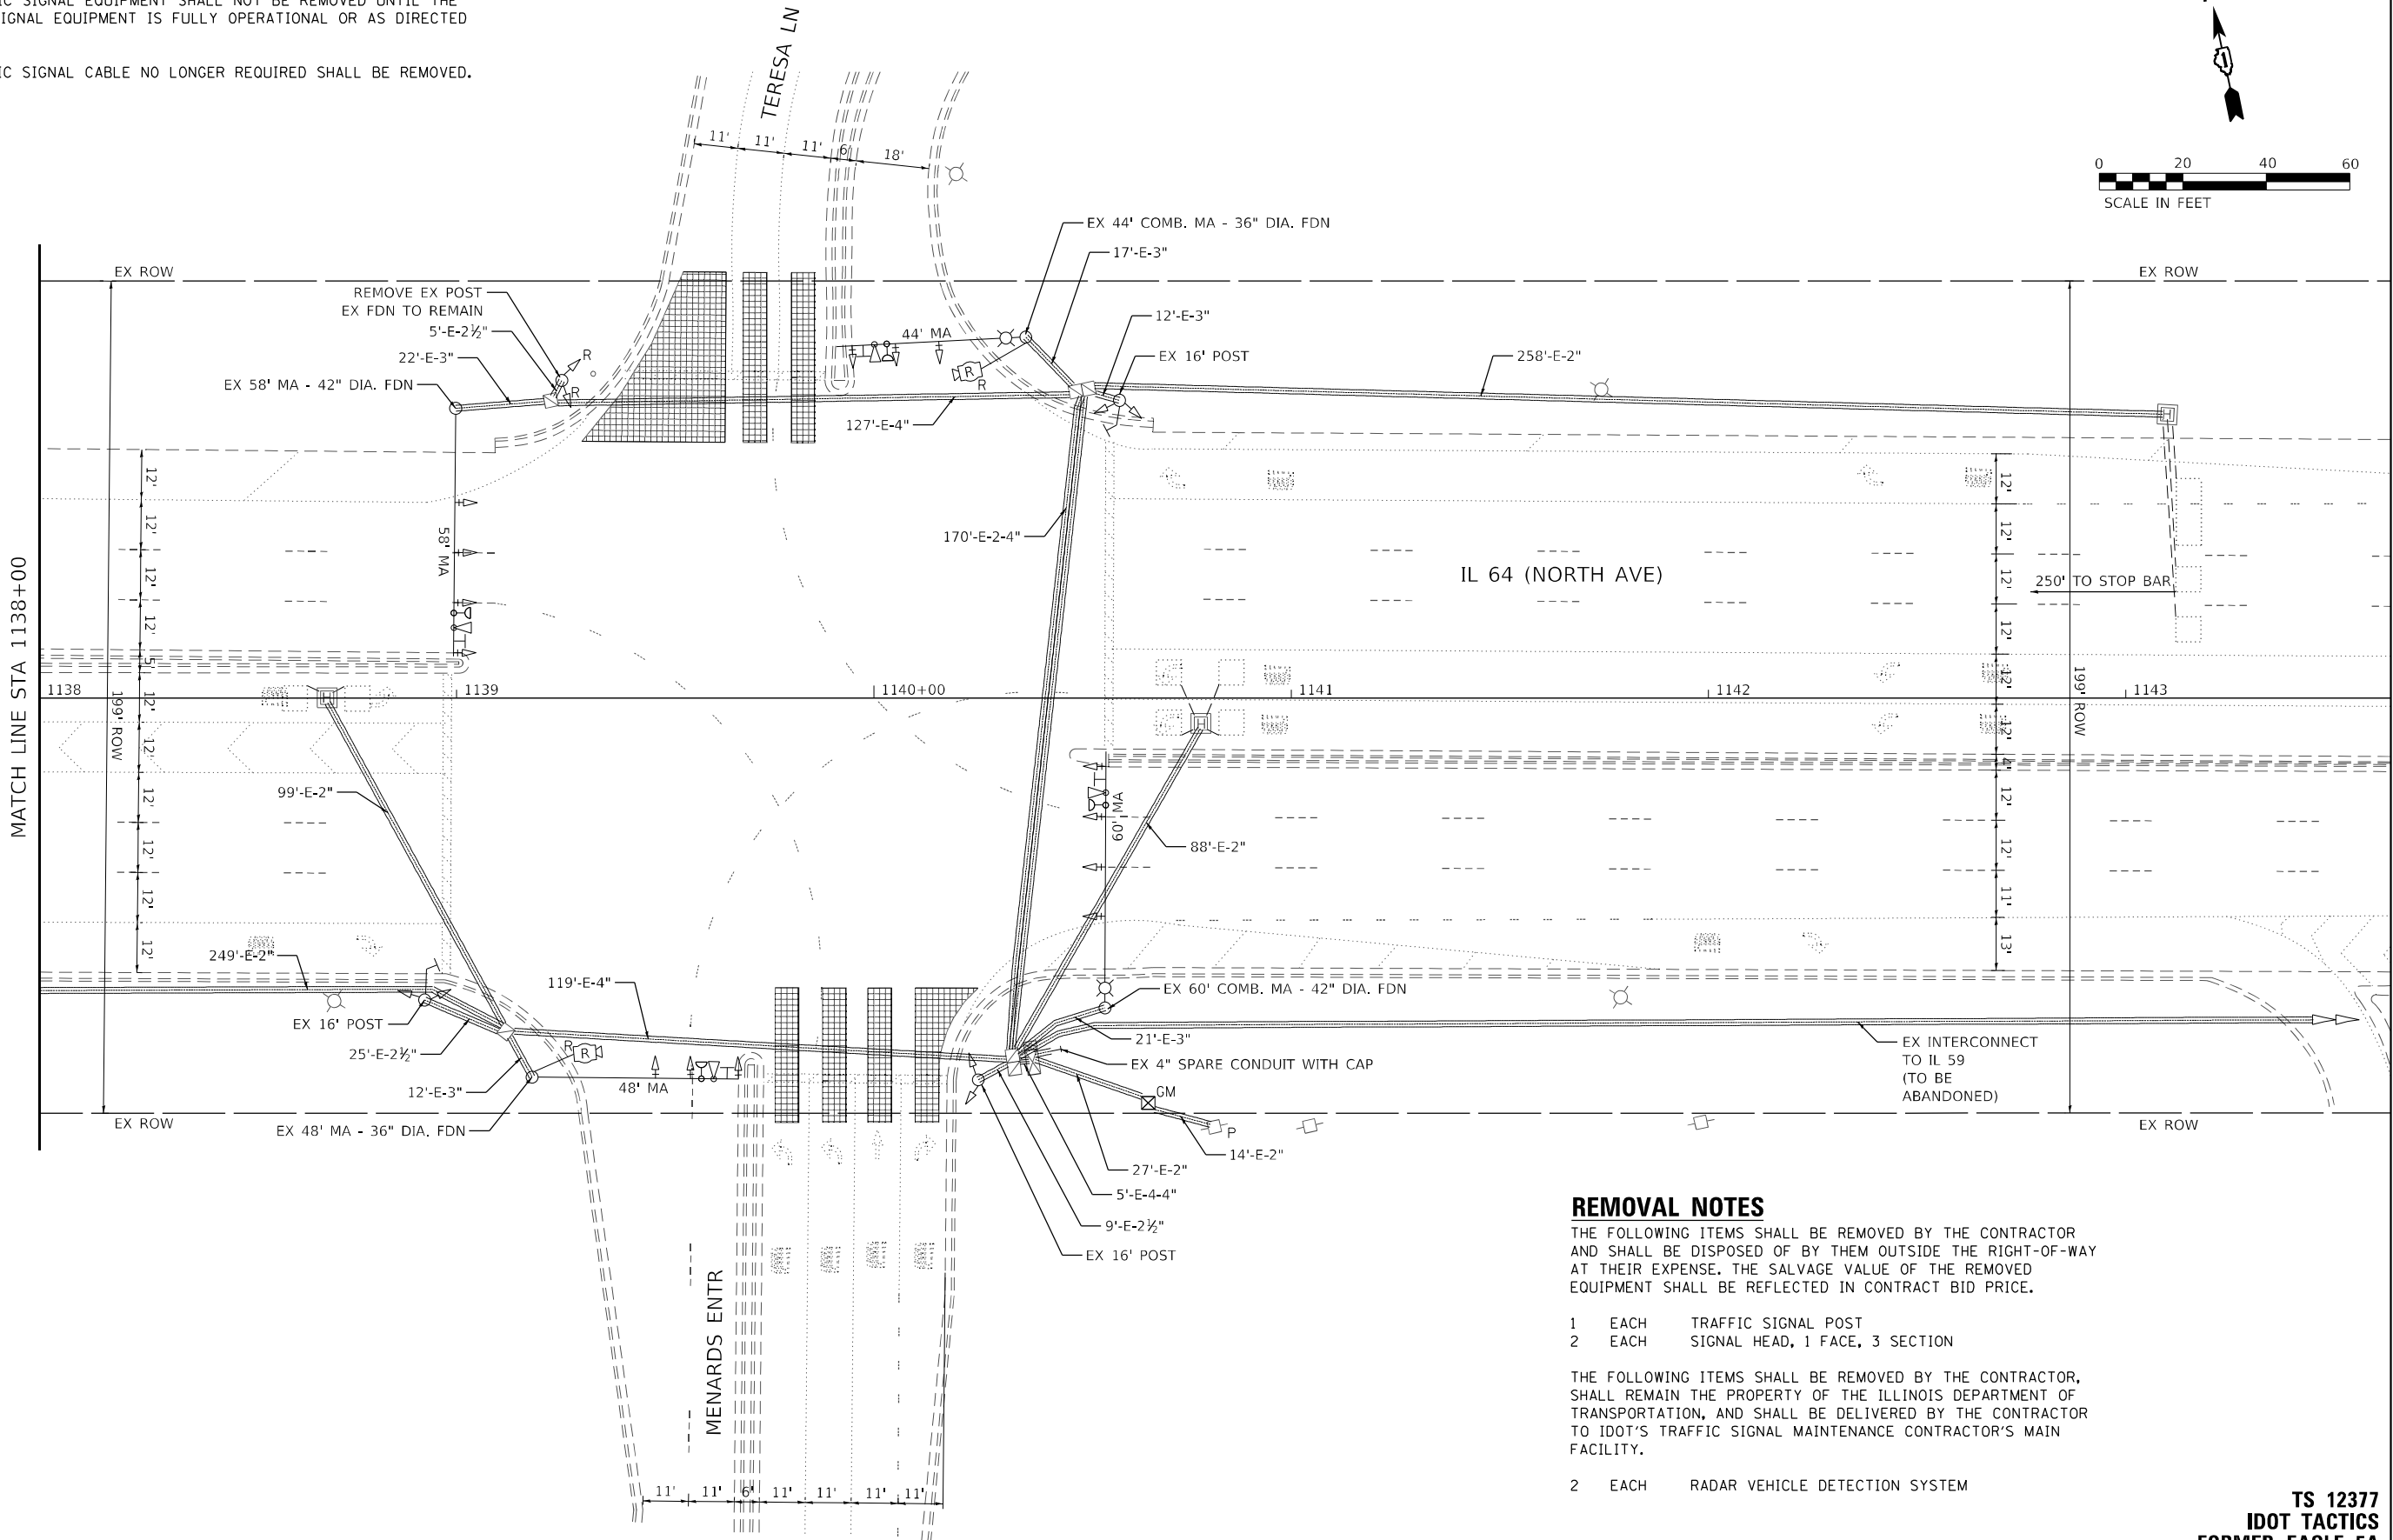

REMOVAL NOTES

THE FOLLOWING ITEMS SHALL BE REMOVED BY THE CONTRACTOR AND SHALL BE DISPOSED OF BY THEM OUTSIDE THE RIGHT-OF-WAY AT THEIR EXPENSE. THE SALVAGE VALUE OF THE REMOVED EQUIPMENT SHALL BE REFLECTED IN CONTRACT BID PRICE.

- 1 EACH TRAFFIC SIGNAL POST
2 EACH SIGNAL HEAD, 1 FACE, 3 SECTION

THE FOLLOWING ITEMS SHALL BE REMOVED BY THE CONTRACTOR, SHALL REMAIN THE PROPERTY OF THE ILLINOIS DEPARTMENT OF TRANSPORTATION, AND SHALL BE DELIVERED BY THE CONTRACTOR TO IDOT'S TRAFFIC SIGNAL MAINTENANCE CONTRACTOR'S MAIN FACILITY.

- 2 EACH RADAR VEHICLE DETECTION SYSTEM

TS 12377
IDOT TACTICS
FORMER EAGLE 5A



© 2023 KIMLEY-HORN AND ASSOCIATES, INC.
4001 WILMINGTON ROAD, SUITE 600
WARREN, ILL. 60555
PHONE: (847) 455-4555
WWW.KIMLEY-HORN.COM


USER NAME =	DESIGNED -	REVISED -
	DRAWN -	REVISED -
PLOT SCALE =	CHECKED -	REVISED -
PLOT DATE =	DATE -	REVISED -

STATE OF ILLINOIS
DEPARTMENT OF TRANSPORTATION

TRAFFIC SIGNAL EQUIPMENT REMOVAL PLAN
IL 64 (NORTH AVE) AND TERESA LN/MENARDS ENTR

SCALE: 1" = 20' SHEET OF SHEETS STA. TO STA.

F.A.P. RTE.	SECTION	COUNTY	TOTAL SHEETS	SHEET NO.
307	2020-263-SUR, SW&TS	DUPAGE	529	132
CONTRACT NO. 62N33				
ILLINOIS FED. AID PROJECT				

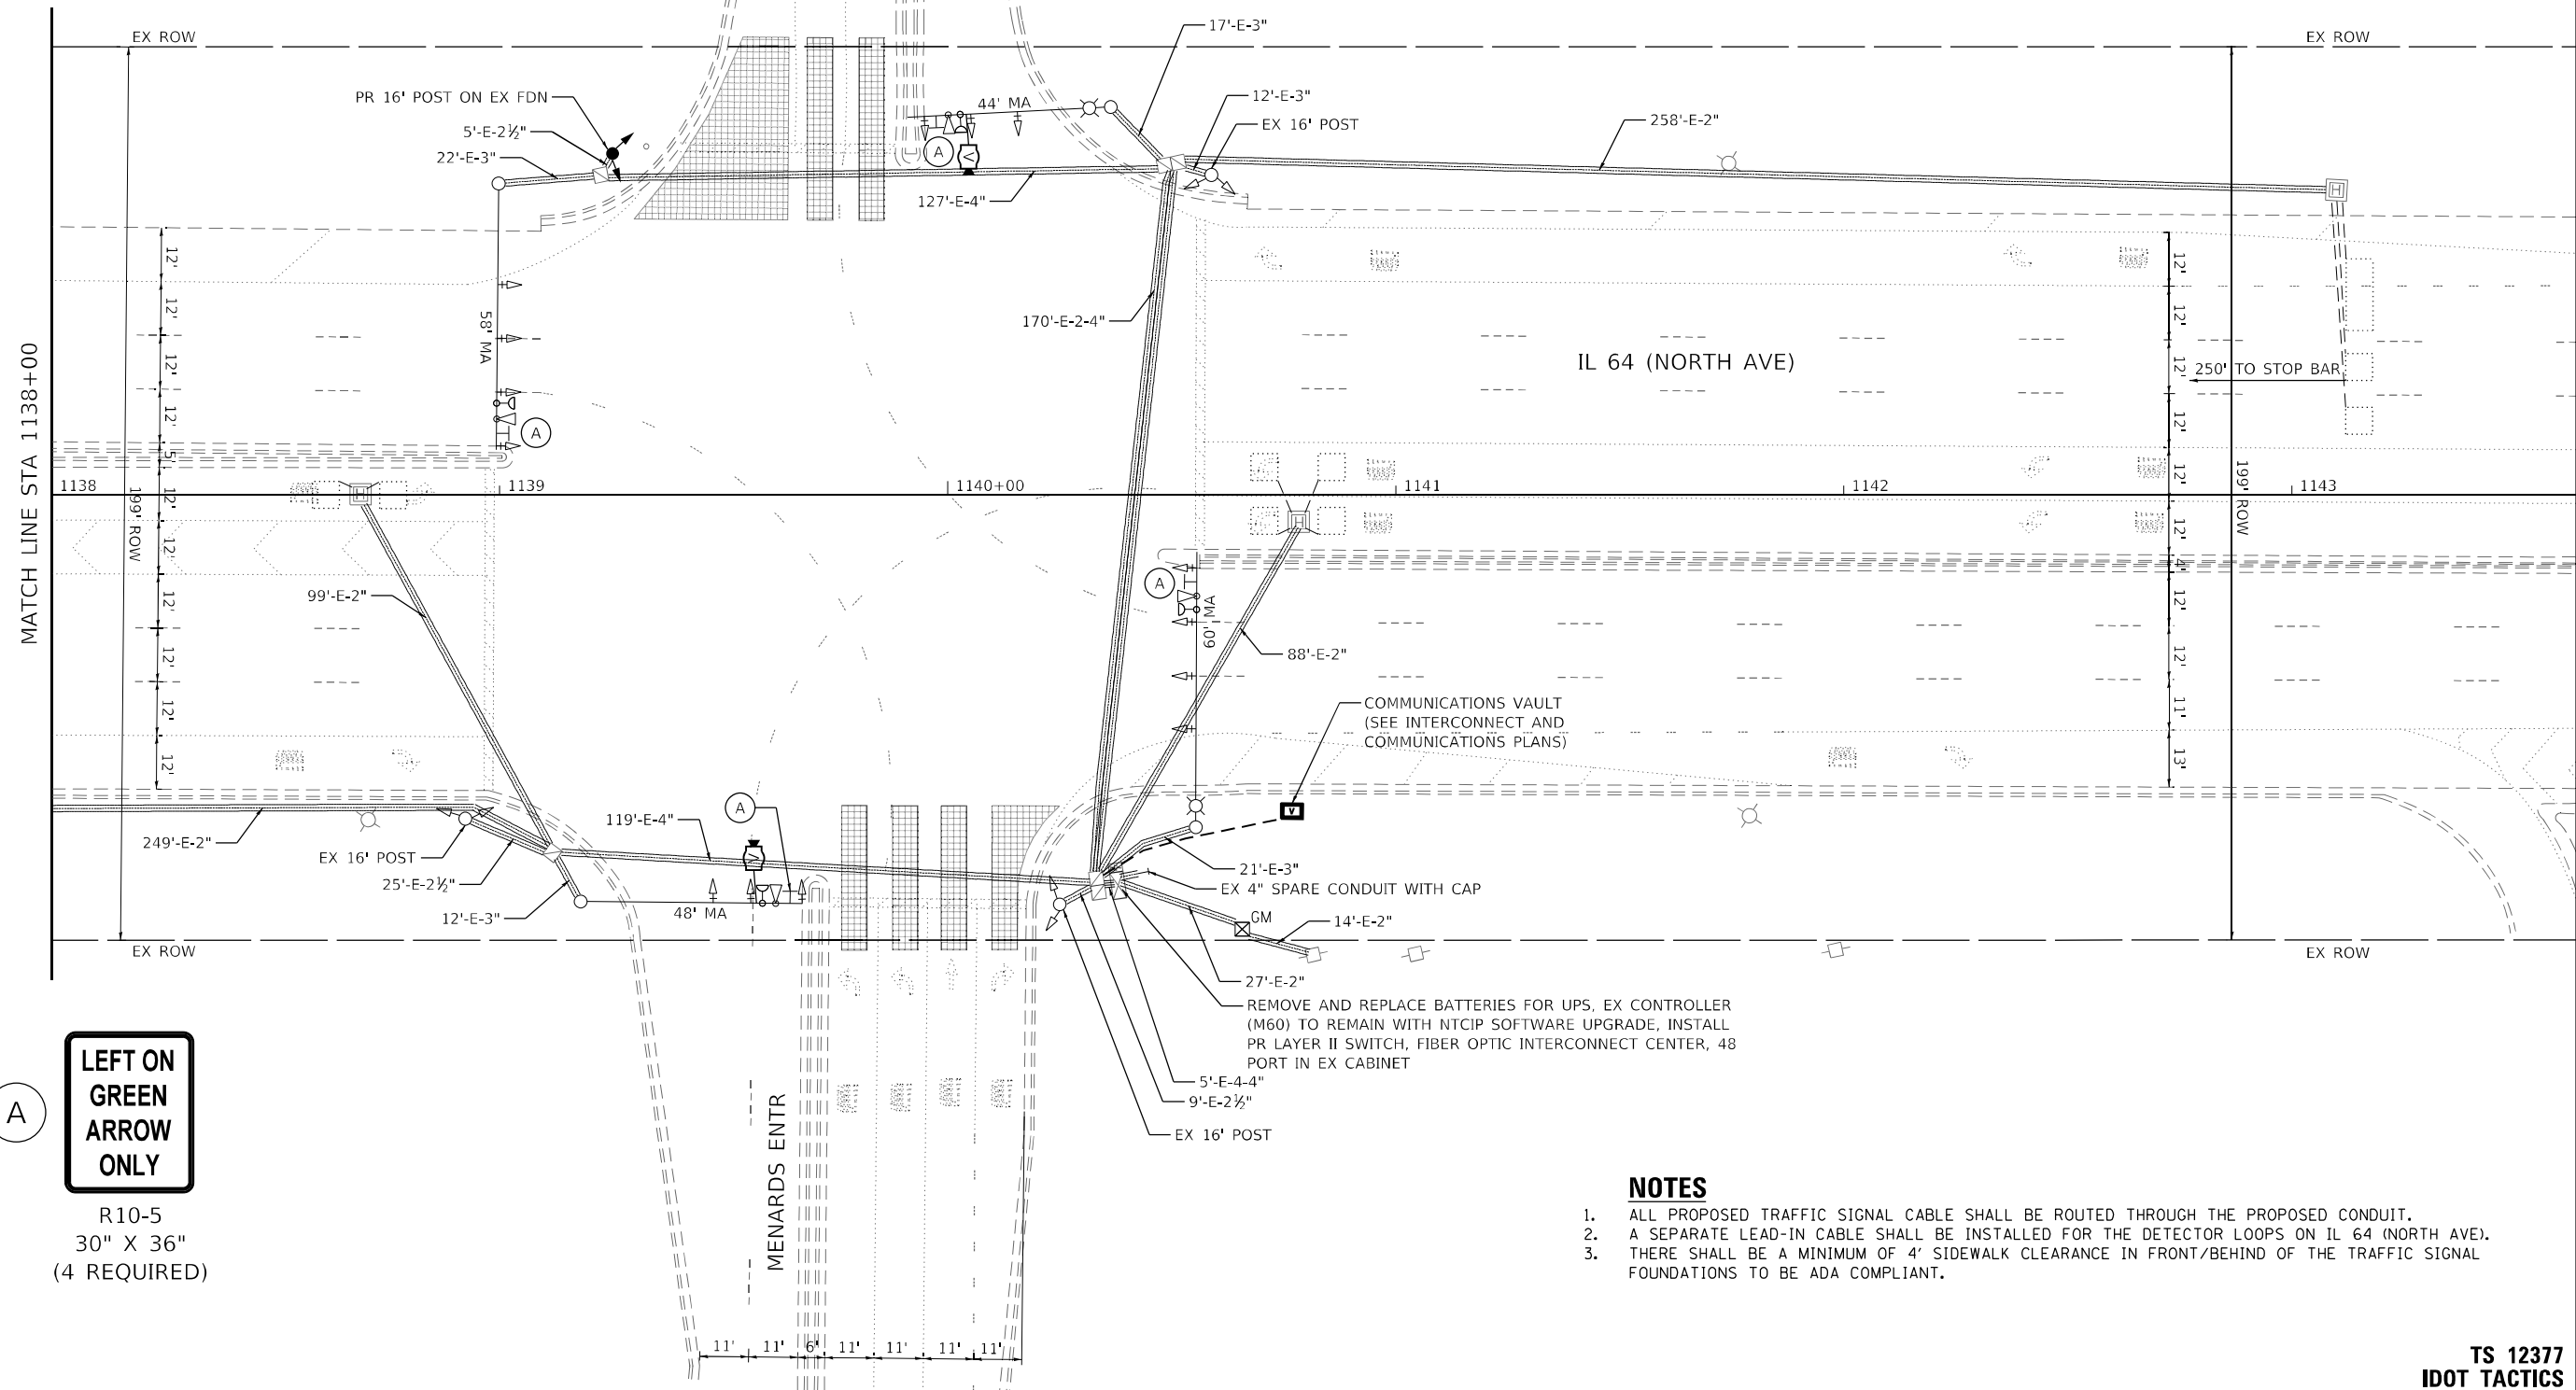

**LEFT ON
GREEN
ARROW
ONLY**

R10-5
30" X 36"
(4 REQUIRED)

- NOTES**
1. ALL PROPOSED TRAFFIC SIGNAL CABLE SHALL BE ROUTED THROUGH THE PROPOSED CONDUIT.
 2. A SEPARATE LEAD-IN CABLE SHALL BE INSTALLED FOR THE DETECTOR LOOPS ON IL 64 (NORTH AVE).
 3. THERE SHALL BE A MINIMUM OF 4' SIDEWALK CLEARANCE IN FRONT/BEHIND OF THE TRAFFIC SIGNAL FOUNDATIONS TO BE ADA COMPLIANT.

**TS 12377
IDOT TACTICS
FORMER EAGLE 5A**

MODEL: Default
FILE: \\usidp-prod\usidp-bentley.com\ksh-pw-d1\Documents\01 Active Projects\IMW-CHS-68095\00 - IL 64\Phase 1\12 Design\CAD\Plan_Sheets\Signal\West_Corridor_Signal\011211-14-14-ts-31_KIM.dgn





USER NAME =	DESIGNED -	REVISED -
DRAWN -	REVIS	
PLOT SCALE =	CHECKED -	REVISED -
PLOT DATE =	DATE -	REVISED -

**STATE OF ILLINOIS
DEPARTMENT OF TRANSPORTATION**

**TRAFFIC SIGNAL MODERNIZATION PLAN
IL 64 (NORTH AVE) AND TERESA LN/MENARDS ENTR**

SCALE: 1" = 20' SHEET OF SHEETS STA. TO STA.

F.A.P. RTE.	SECTION	COUNTY	TOTAL SHEETS	SHEET NO.
307	2020-263-SUR,SW&TS	DUPAGE	529	134
CONTRACT NO. 62N33				
ILLINOIS FED. AID PROJECT				

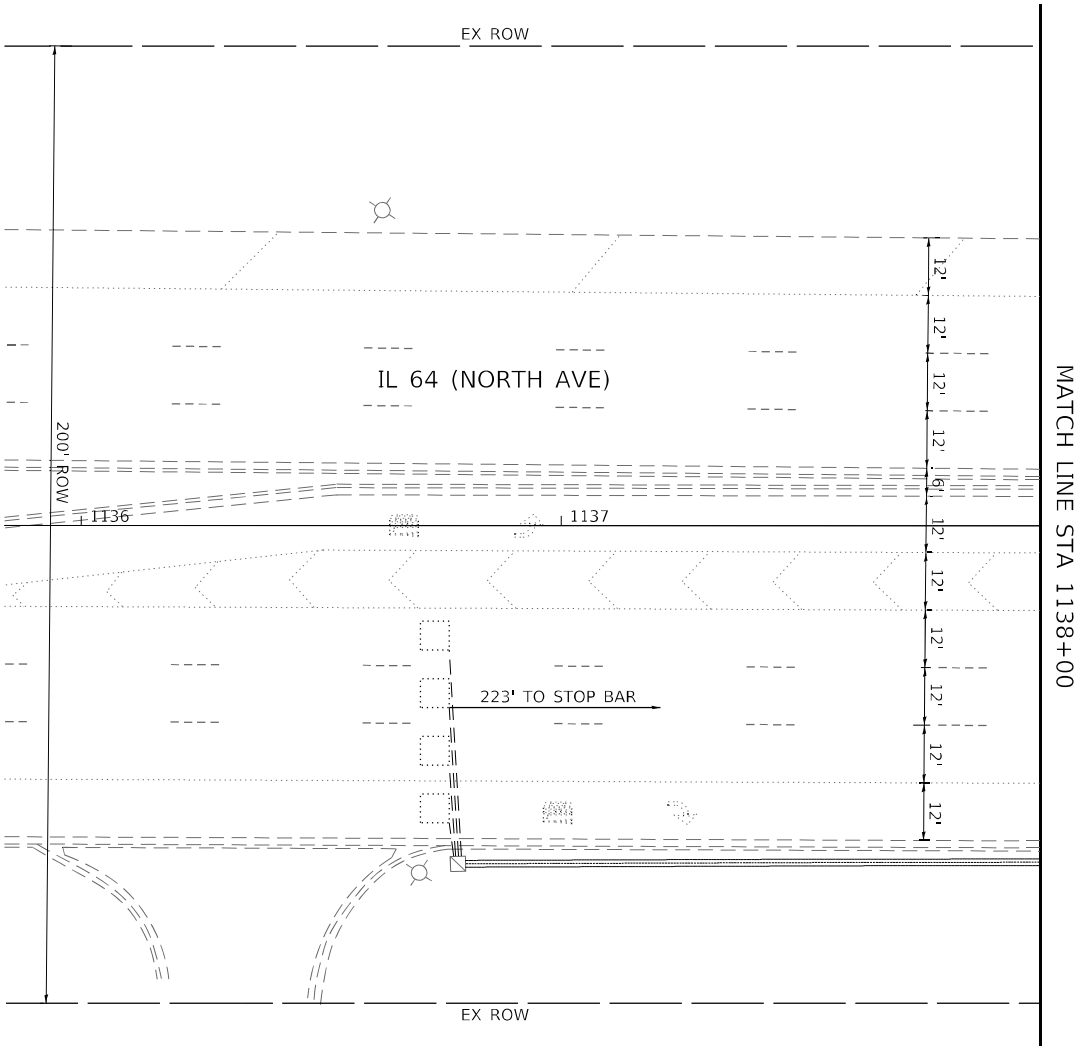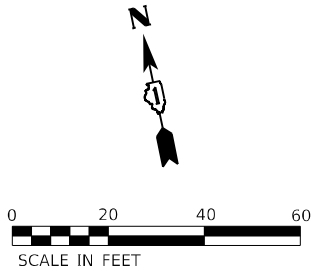

MODEL: Default
FILE NAME: p:\sub-pw\bartley.com\khp-w-d\Documents\01 Active Projects\MW\CL-S-160950\00 - IL 64\Phase 1\2 Design\CAD\Plan Streets\Signal\West Corridor_Signal\01081714-IL-64-32_KIM.dgn



USER NAME =	DESIGNED -	REVISED -
	DRAWN -	REVISED -
PLOT SCALE =	CHECKED -	REVISED -
PLOT DATE =	DATE -	REVISED -


STATE OF ILLINOIS
DEPARTMENT OF TRANSPORTATION

TRAFFIC SIGNAL MODERNIZATION PLAN
IL 64 (NORTH AVE) AND TERESA LN/MENARDS ENTR


SCALE: 1" = 20' SHEET OF SHEETS STA. TO STA.

TS 12377 IDOT TACTICS FORMER EAGLE 5A		F.A.P. RTE.	SECTION	COUNTY	TOTAL SHEETS	SHEET NO.
		307	2020-263-SUR,SW&TS	DUPAGE	529	135
		CONTRACT NO. 62N33				
		ILLINOIS FED. AID PROJECT				

EXISTING AND PROPOSED CONTROLLER SEQUENCE

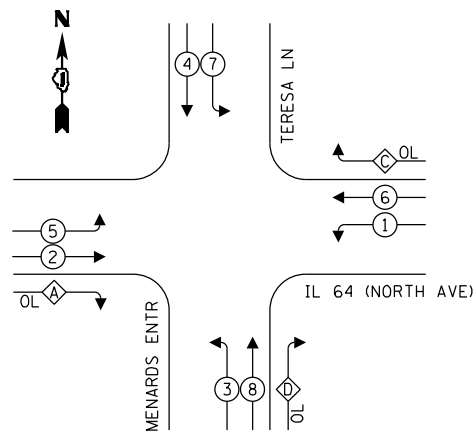


LEGEND:

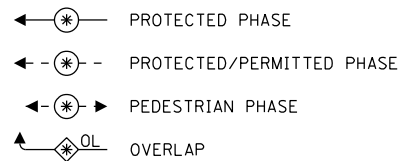

OVERLAP LETTER		PERMISSIVE PHASE		PROTECTED PHASE
A	=	2	+	3
C	=	6	+	7
D	=	8	+	1

EXISTING AND PROPOSED EMERGENCY VEHICLE PREEMPTION SEQUENCE

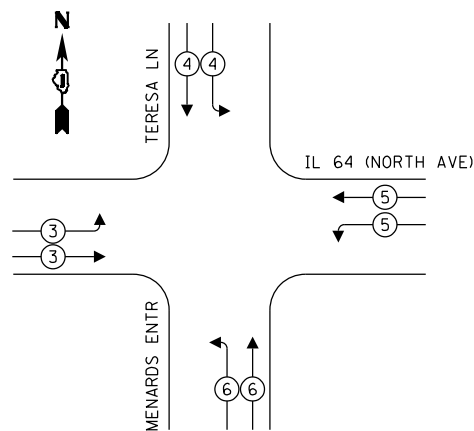

TRAFFIC SIGNAL ELECTRICAL SERVICE REQUIREMENTS

TYPE	QUANTITY	UNIT WATTAGE	TOTAL WATTAGE
SIGNAL HEAD 1 OR 3-SECTION	16	11	176
4-SECTION	-	14	-
5-SECTION	6	13	78
PROGRAMMABLE 3-SECTION	-	22	-
4-SECTION	-	32	-
5-SECTION	-	28	-
PEDESTRIAN SIGNAL	-	15	-
CONTROLLER	1	150	150
MASTER CONTROLLER	-	100	-
UPS	1	25	25
DETECTION VIDEO	2	20	40
BLANK-OUT SIGN	-	25	-
NETWORK SWITCH LAYER II OR III	1	35	35
CELLULAR MODEM	-	15	-
TOTAL UPS SIZING			504
UPS CHARGING	1	225	225
BATTERY HEATER MAT	1	180	180
CABINET HEATER	1	200	200
FLASHER	-	15	-
LED STREET NAME SIGN	-	120	-
LUMINAIRE	-	240	-
TOTAL SERVICE WIRE SIZING			1109

ENERGY COSTS TO:
CITY OF WEST CHICAGO
475 MAIN ST
WEST CHICAGO, IL 60185


ENERGY SUPPLY: COMPANY: COMED
PHONE: (866) 639-3532
ACCOUNT NUMBER: 73470-49055

LEGEND:

L = LED LAMP MODULE REPLACEMENT
* = ROADWAY LIGHTING CABLE

CABLE PLAN

(NOT TO SCALE)

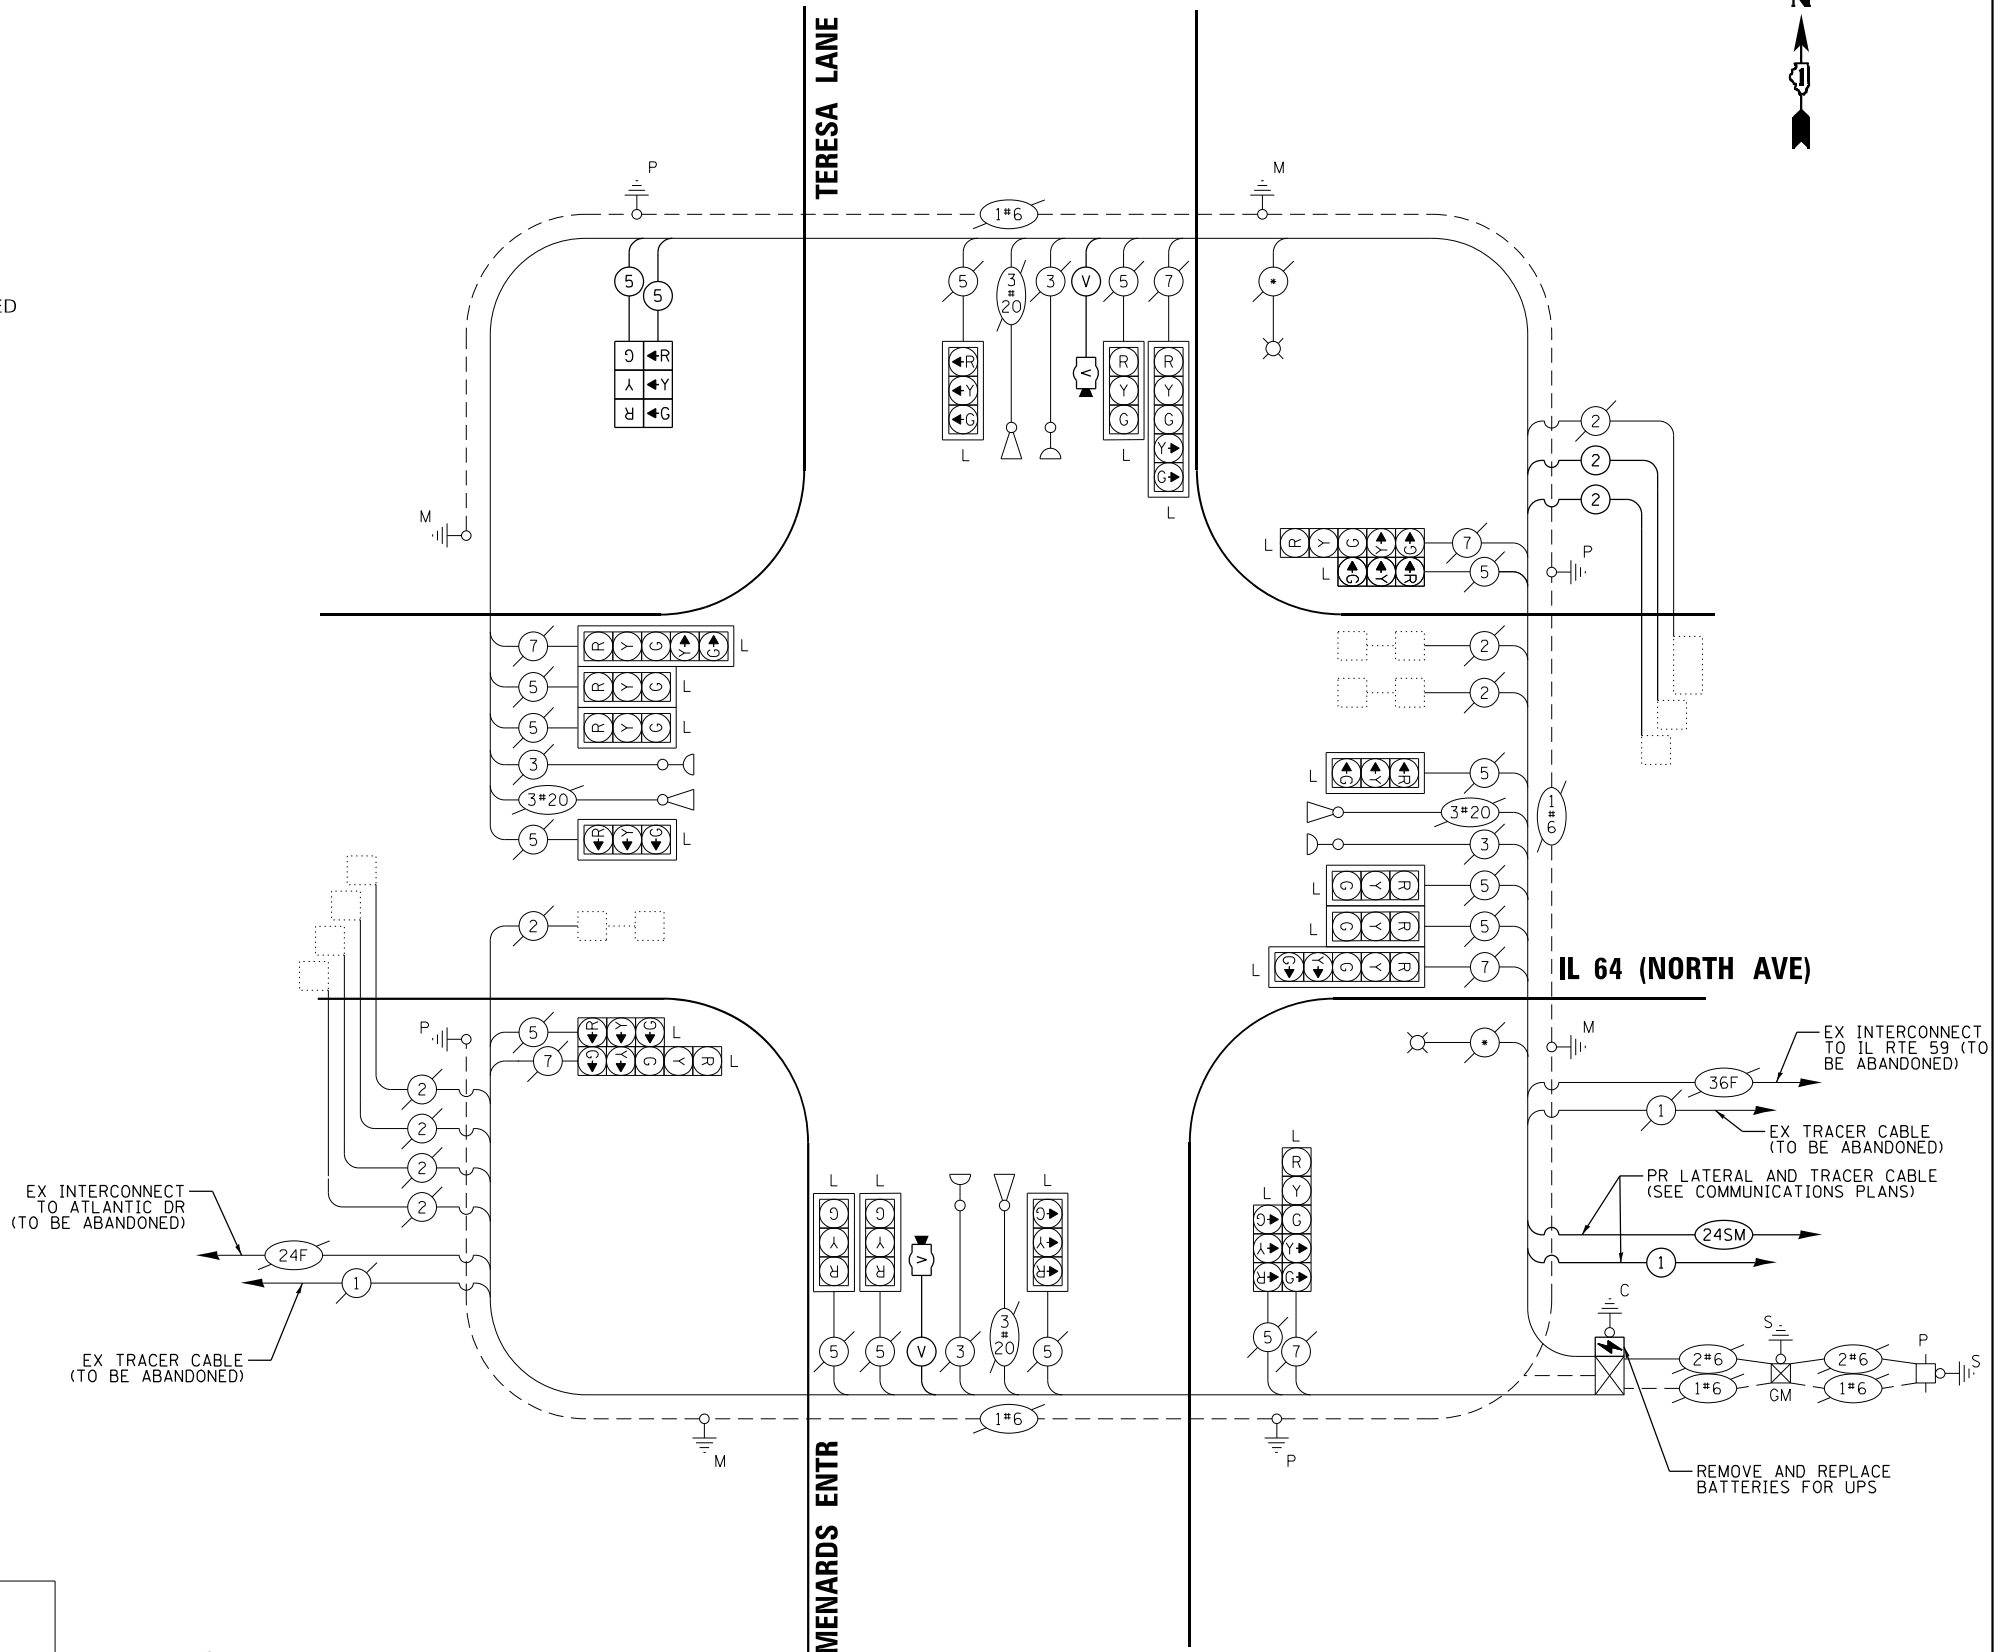

TS 12377
IDOT TACTICS
FORMER EAGLE 5A

Kimley»»Horn

© 2023 KIMLEY-HORN AND ASSOCIATES, INC.
4201 WINTFIELD ROAD, SUITE 603
WARRENVILLE, IL 60555
PHONE: 630-487-5550
WWW.KIMLEY-HORN.COM

USER NAME	=
PLOT SCALE	=
PLOT DATE	=

DESIGNED -
DRAWN -
CHECKED -
DATE -

REVISED	-
REVISED	-
REVISED	-
REVISED	-

STATE OF ILLINOIS
DEPARTMENT OF TRANSPORTATION

**CABLE PLAN, PHASE DESIGNATION DIAGRAM, AND
EMERGENCY VEHICLE PREEMPTION SEQUENCE
IL 64 (NORTH AVE) AND TERESA LN/MENARDS ENTR**

SCALE: N.T.S.	SHEET	OF	SHEETS	STA.	TO STA.
---------------	-------	----	--------	------	---------


F.A.P. RTE.	SECTION	COUNTY	TOTAL SHEETS	SHEET NO.
307	2020-263-SUR,SW&TS	DUPAGE	529	136
CONTRACT NO. 62N33				
ILLINOIS		FED. AID PROJECT		

SCHEDULE OF QUANTITIES

ITEM DESCRIPTION	UNIT	QUANTITY
MAINTENANCE OF EXISTING TRAFFIC SIGNAL INSTALLATION	EACH	1
ELECTRIC CABLE IN CONDUIT, SIGNAL NO. 14 5C	FOOT	730
ELECTRIC CABLE IN CONDUIT, LEAD-IN, NO. 14 1 PAIR	FOOT	1377
TRAFFIC SIGNAL POST, GALVANIZED STEEL 16 FT.	EACH	1
SIGNAL HEAD, LED, 1-FACE, 3-SECTION, BRACKET MOUNTED	EACH	2
INDUCTIVE LOOP DETECTOR	EACH	2
REMOVE ELECTRIC CABLE FROM CONDUIT	FOOT	730
REMOVE EXISTING TRAFFIC SIGNAL EQUIPMENT	EACH	1
LED LAMP MODULE REPLACEMENT	EACH	72
LAYER II (DATALINK) SWITCH	EACH	1
TERMINATE FIBER IN CABINET	EACH	12
UPGRADE EXISTING CONTROLLER TO NTCIP SPECIAL	EACH	1
TACTICS LICENSE EXPANSION	EACH	1
REMOVE AND REPLACE BATTERIES FOR UNINTERRUPTABLE POWER SUPPLY, EXTENDED	EACH	1
FIBER OPTIC INTERCONNECT CENTER, 48 PORT	EACH	1
LED SIGNAL FACE, LENS COVER	EACH	22
VIDEO VEHICLE DETECTION SYSTEM, SINGLE APPROACH	EACH	2

TS 12377
IDOT TACTICS
FORMER EAGLE 5A

Kimley»Horn © 2023 KIMLEY-HORN AND ASSOCIATES, INC. 4001 SHILOH D. ROAD, SUITE 600 VARRICK, I.E.B. 60885 PHONE: 630-487-6550 WWW.KH-BY-HORN.COM	USER NAME =	DESIGNED -	REVISED -	STATE OF ILLINOIS DEPARTMENT OF TRANSPORTATION	SCHEDULE OF QUANTITIES IL 64 (NORTH AVE) AND TERESA LVMENARDS ENTR				F.A.P. RTE.	SECTION	COUNTY	TOTAL SHEETS	SHEET NO.
		DRAWN -	REVISED -		307	2020-263-SUR, SW&TS	DUPAGE	529	137				
	PLOT SCALE =	CHECKED -	REVISED -		CONTRACT NO. 62N33								
	PLOT DATE =	DATE	REVISED -		SCALE: N.T.S.	SHEET	OF	SHEETS	STA.	TO STA.			

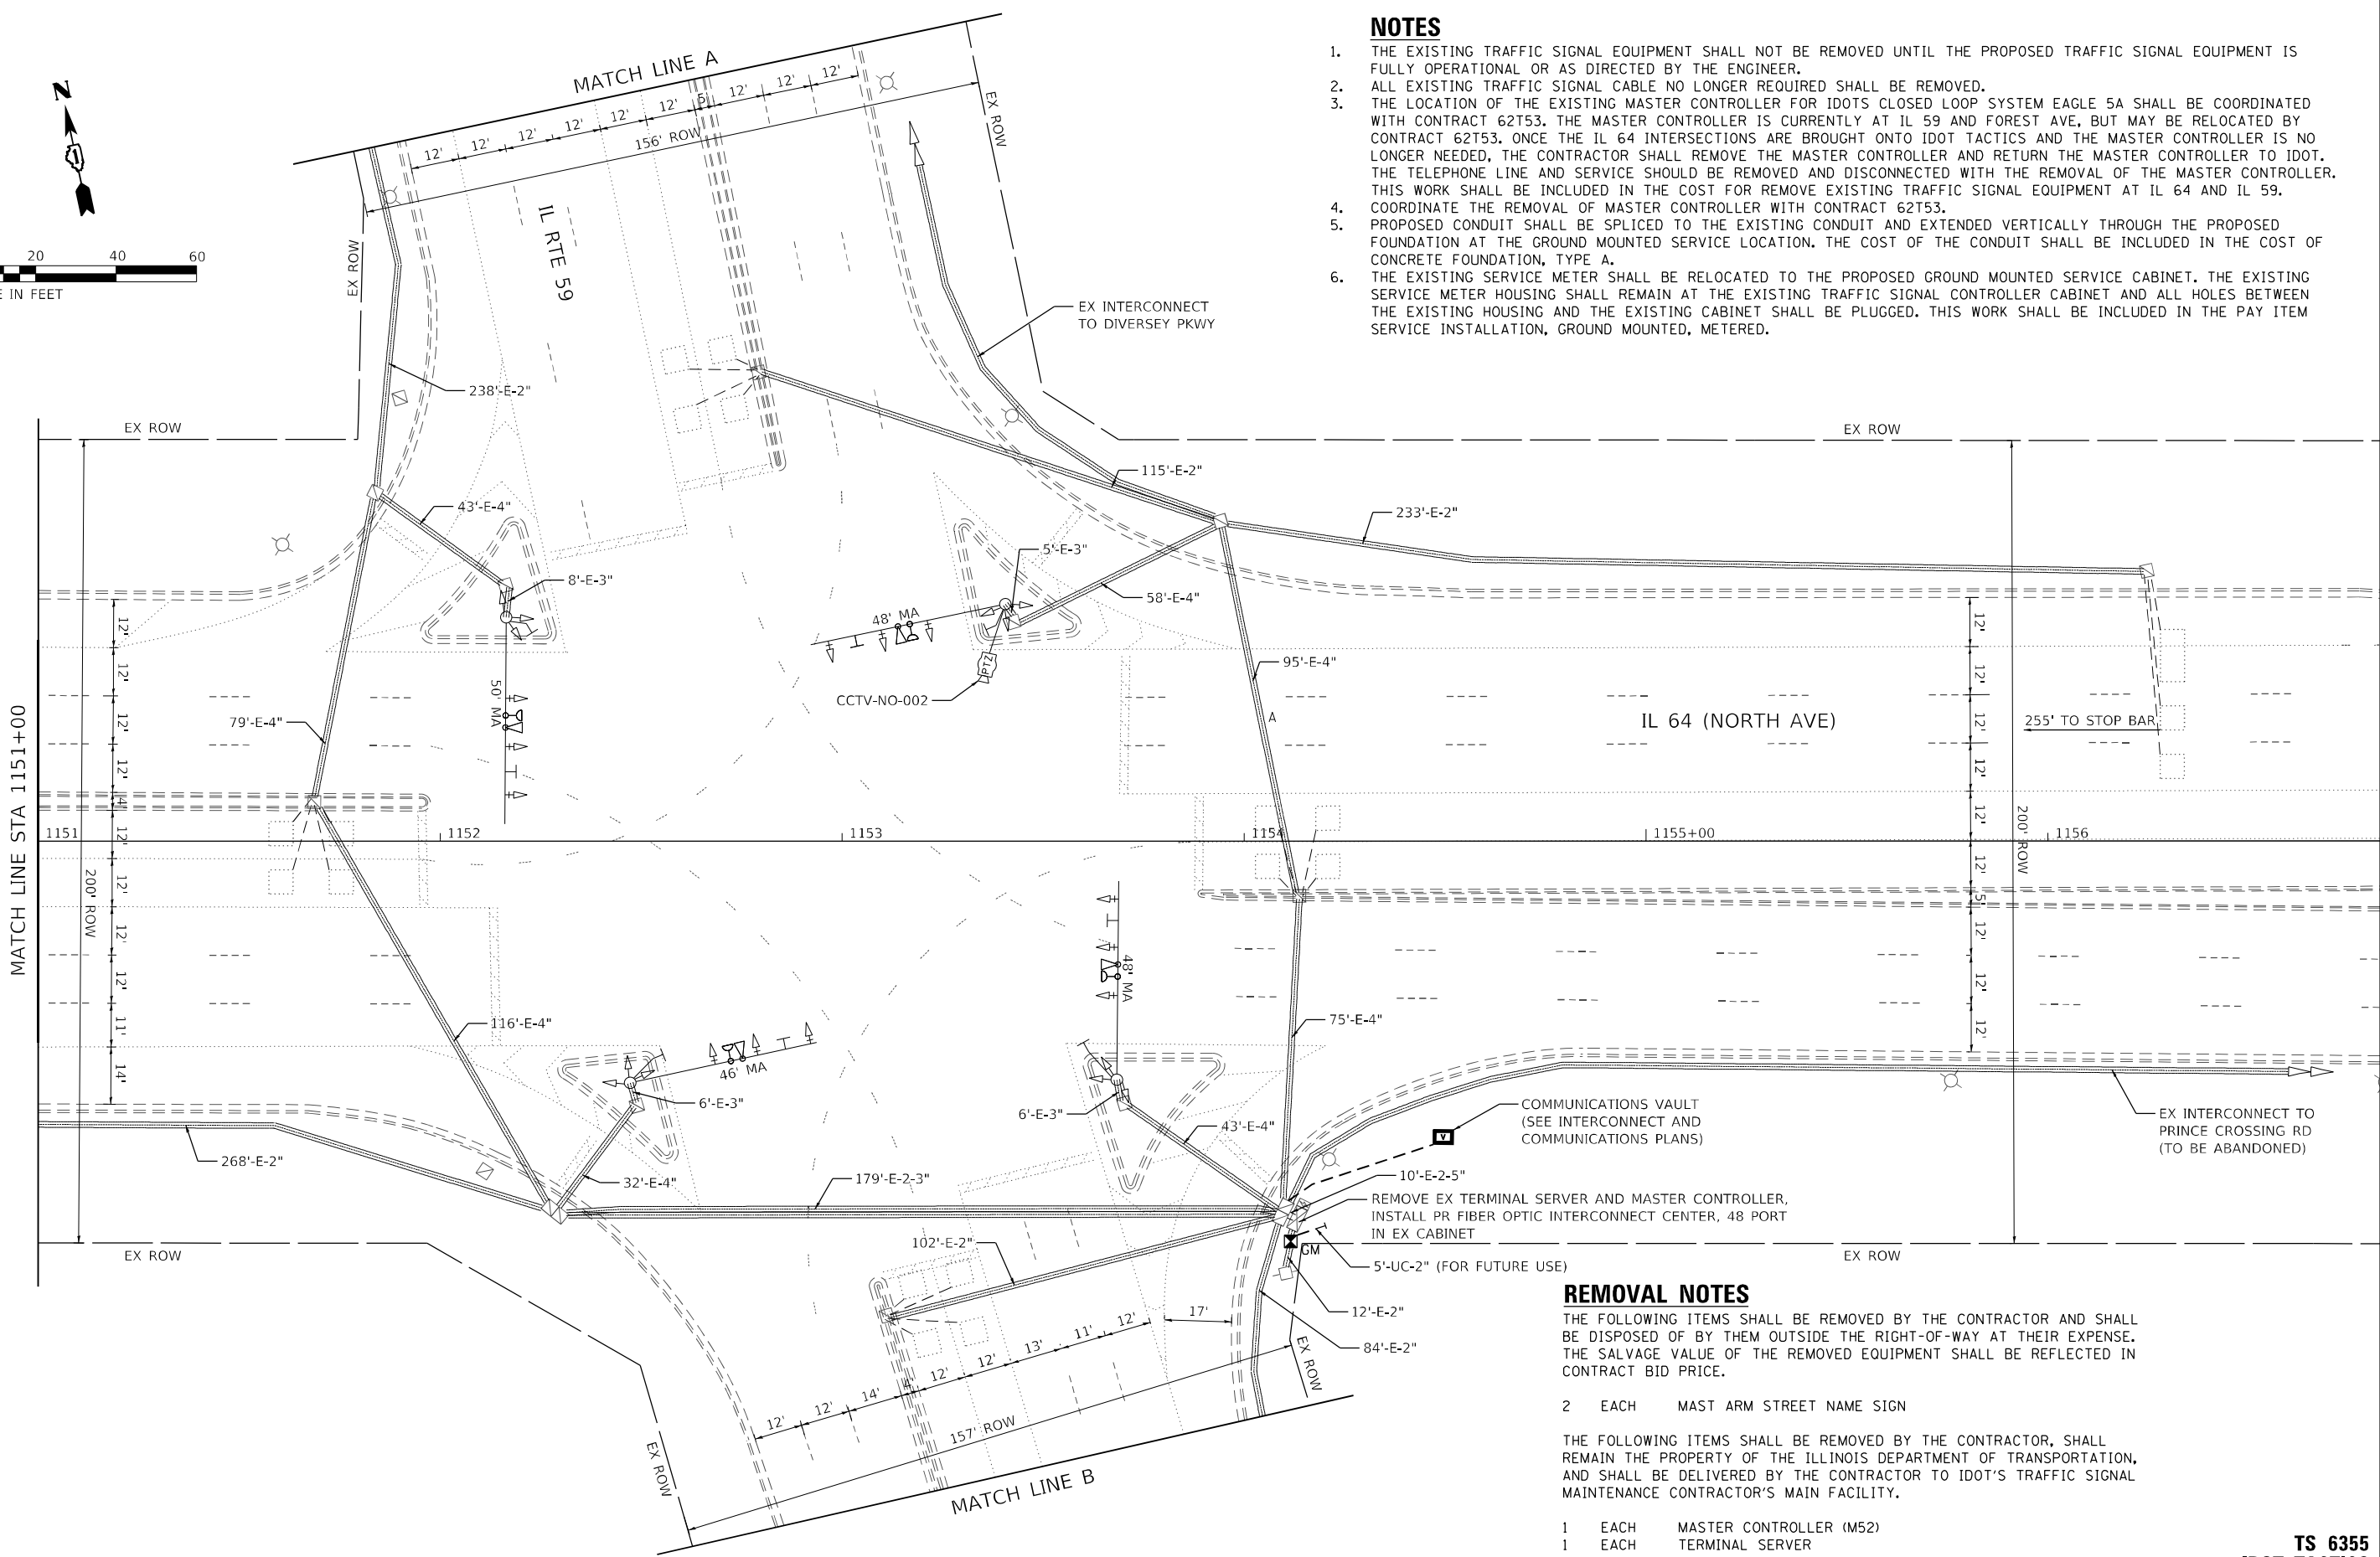

NOTES

1. THE EXISTING TRAFFIC SIGNAL EQUIPMENT SHALL NOT BE REMOVED UNTIL THE PROPOSED TRAFFIC SIGNAL EQUIPMENT IS FULLY OPERATIONAL OR AS DIRECTED BY THE ENGINEER.
2. ALL EXISTING TRAFFIC SIGNAL CABLE NO LONGER REQUIRED SHALL BE REMOVED.
3. THE LOCATION OF THE EXISTING MASTER CONTROLLER FOR IDOT'S CLOSED LOOP SYSTEM EAGLE 5A SHALL BE COORDINATED WITH CONTRACT 62T53. THE MASTER CONTROLLER IS CURRENTLY AT IL 59 AND FOREST AVE, BUT MAY BE RELOCATED BY CONTRACT 62T53. ONCE THE IL 64 INTERSECTIONS ARE BROUGHT ONTO IDOT TACTICS AND THE MASTER CONTROLLER IS NO LONGER NEEDED, THE CONTRACTOR SHALL REMOVE THE MASTER CONTROLLER AND RETURN THE MASTER CONTROLLER TO IDOT. THE TELEPHONE LINE AND SERVICE SHOULD BE REMOVED AND DISCONNECTED WITH THE REMOVAL OF THE MASTER CONTROLLER. THIS WORK SHALL BE INCLUDED IN THE COST FOR REMOVE EXISTING TRAFFIC SIGNAL EQUIPMENT AT IL 64 AND IL 59.
4. COORDINATE THE REMOVAL OF MASTER CONTROLLER WITH CONTRACT 62T53.
5. PROPOSED CONDUIT SHALL BE SPLICED TO THE EXISTING CONDUIT AND EXTENDED VERTICALLY THROUGH THE PROPOSED FOUNDATION AT THE GROUND MOUNTED SERVICE LOCATION. THE COST OF THE CONDUIT SHALL BE INCLUDED IN THE COST OF CONCRETE FOUNDATION, TYPE A.
6. THE EXISTING SERVICE METER SHALL BE RELOCATED TO THE PROPOSED GROUND MOUNTED SERVICE CABINET. THE EXISTING SERVICE METER HOUSING SHALL REMAIN AT THE EXISTING TRAFFIC SIGNAL CONTROLLER CABINET AND ALL HOLES BETWEEN THE EXISTING HOUSING AND THE EXISTING CABINET SHALL BE PLUGGED. THIS WORK SHALL BE INCLUDED IN THE PAY ITEM SERVICE INSTALLATION, GROUND MOUNTED, METERED.

REMOVAL NOTES

THE FOLLOWING ITEMS SHALL BE REMOVED BY THE CONTRACTOR AND SHALL BE DISPOSED OF BY THEM OUTSIDE THE RIGHT-OF-WAY AT THEIR EXPENSE. THE SALVAGE VALUE OF THE REMOVED EQUIPMENT SHALL BE REFLECTED IN CONTRACT BID PRICE.

- 2 EACH MAST ARM STREET NAME SIGN
- THE FOLLOWING ITEMS SHALL BE REMOVED BY THE CONTRACTOR, SHALL REMAIN THE PROPERTY OF THE ILLINOIS DEPARTMENT OF TRANSPORTATION, AND SHALL BE DELIVERED BY THE CONTRACTOR TO IDOT'S TRAFFIC SIGNAL MAINTENANCE CONTRACTOR'S MAIN FACILITY.
- 1 EACH MASTER CONTROLLER (M52)
1 EACH TERMINAL SERVER

TS 6355
IDOT TACTICS
FORMER EAGLE 5A

MODEL: Default
FILE: \\uslpc-prod\ut-pw-bentley.com\ktp-pw-d\1\Documents\01 Active Projects\IMW-CL-5-680950\00 - IL 64\Phase II\2 Design\CAD\Plan Sheets\Signal\West Corridor Signal\01-IL-64-35_KIM.dgn

KimleyHorn

© 2021 KIMLEY-HORN AND ASSOCIATES, INC.
4001 WILMINGTON ROAD, SUITE 600
WARREN, IL 60555
PHONE: (847) 455-4555
WWW.KIMLEY-HORN.COM

USER NAME =	DESIGNED -	REVISED -
	DRAWN -	REVISED -
PLOT SCALE =	CHECKED -	REVISED -
PLOT DATE =	DATE -	REVISED -

STATE OF ILLINOIS
DEPARTMENT OF TRANSPORTATION

TRAFFIC SIGNAL MODIFICATION PLAN (SHEET 1 OF 2)
IL 64 (NORTH AVE) AND IL RTE 59

SCALE: 1" = 20' SHEET OF SHEETS STA. TO STA.

F.A.P. RTE.	SECTION	COUNTY	TOTAL SHEETS	SHEET NO.
307	2020-263-SUR, SW&TS	DUPAGE	529	138
				CONTRACT NO. 62N33
		ILLINOIS	FED. AID PROJECT	

MODEL: Default
FILE: \\kimley-horn-bentley.com\khp\p4\1\Documents\01 Active Projects\IMW\CHS-168950\00 - IL 64\Phase 1\2 Design\CAD\Plan_Sheets\Signal\West_Corridor_Signal\01081714-IL-Rt-36_KIM.dgn



USER NAME =	DESIGNED -	REVISED -
	DRAWN -	REVISED -
PLOT SCALE =	CHECKED -	REVISED -
PLOT DATE =	DATE -	REVISED -




STATE OF ILLINOIS
DEPARTMENT OF TRANSPORTATION

TRAFFIC SIGNAL MODIFICATION PLAN (SHEET 2 OF 2)
IL 64 (NORTH AVE) AND IL RTE 59

SCALE: 1" = 20' SHEET OF SHEETS STA. TO STA.


F.A.P. RTE.	SECTION	COUNTY	TOTAL SHEETS	SHEET NO.
307	2020-263-SUR,SW&TS	DUPAGE	529	139
CONTRACT NO. 62N33				
ILLINOIS FED. AID PROJECT				

TS 6355
IDOT TACTICS
FORMER EAGLE 5A

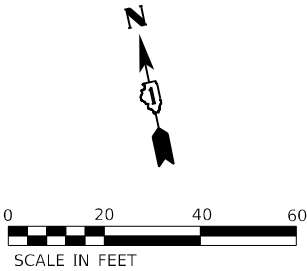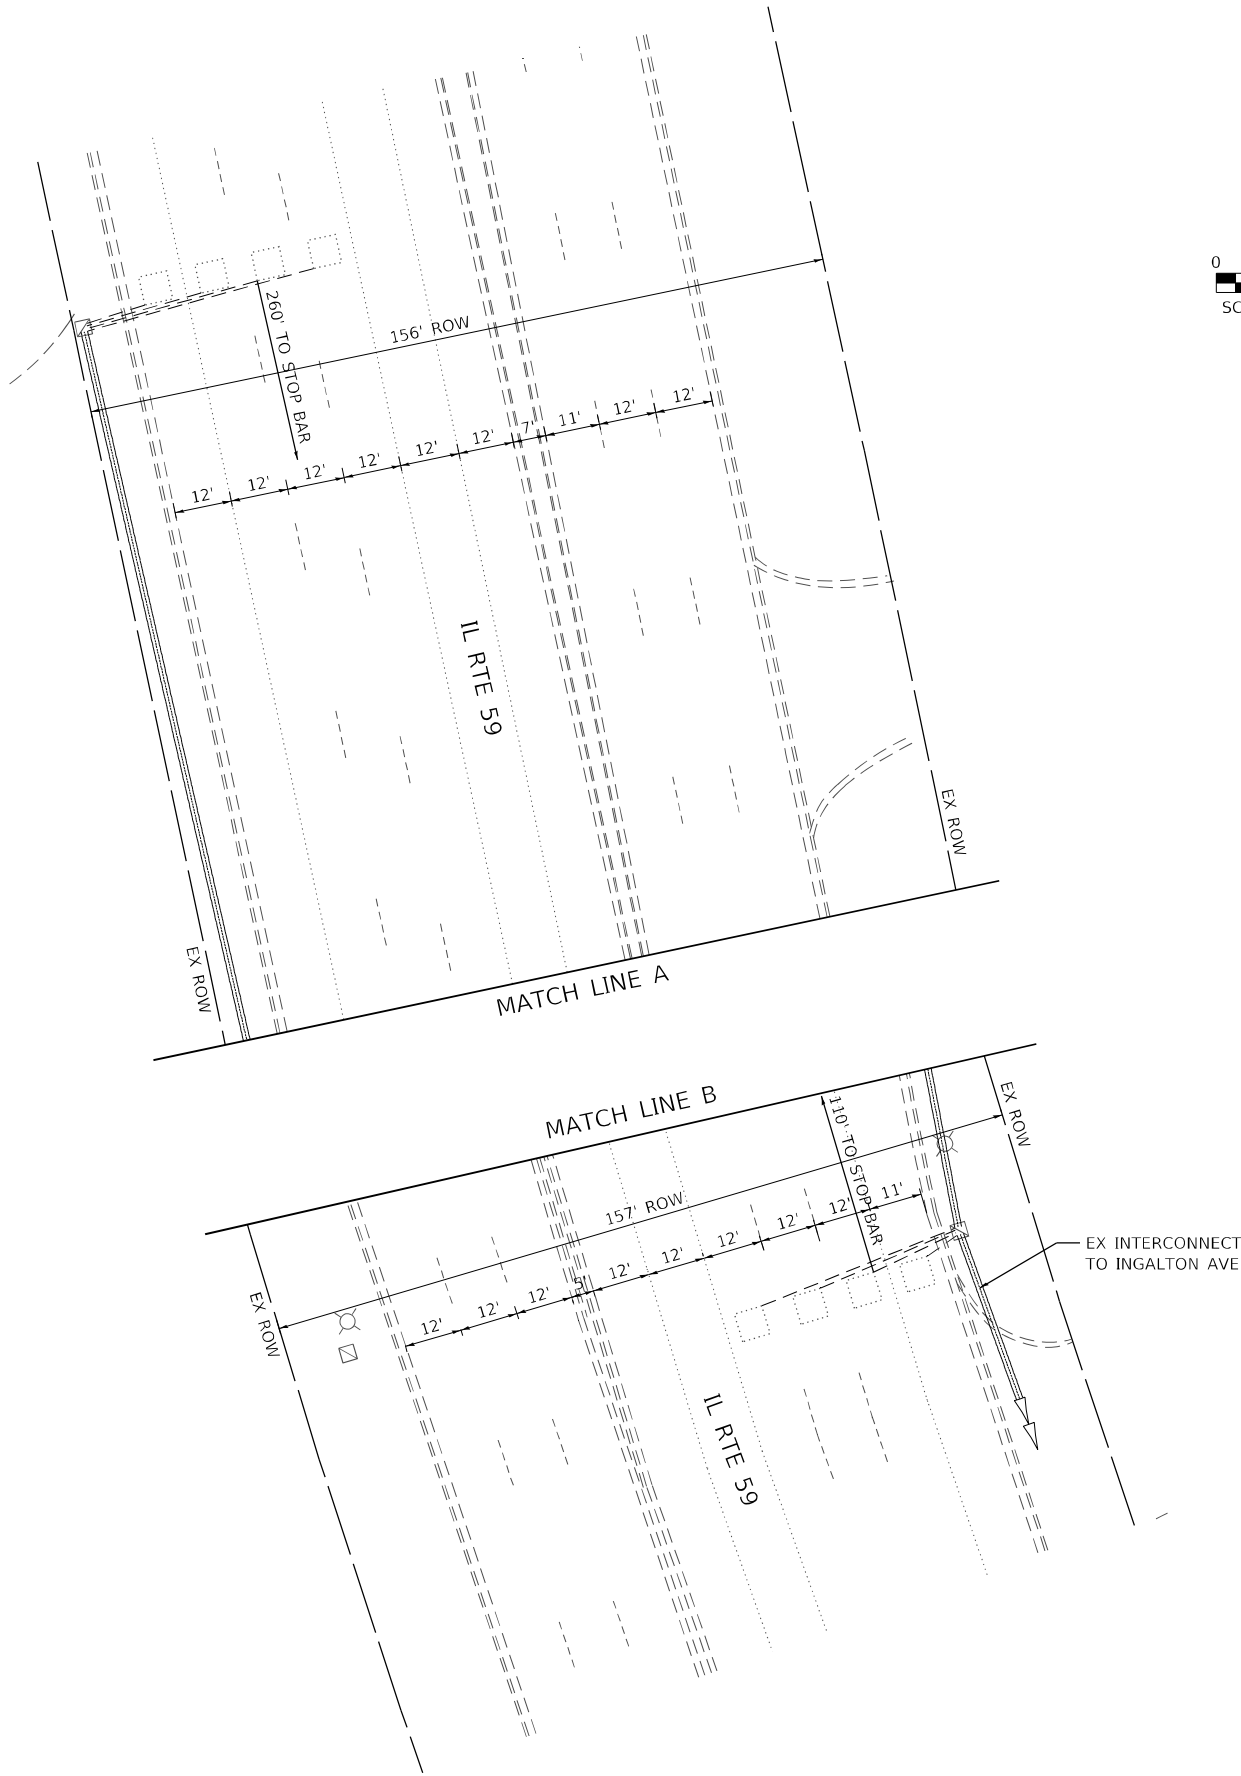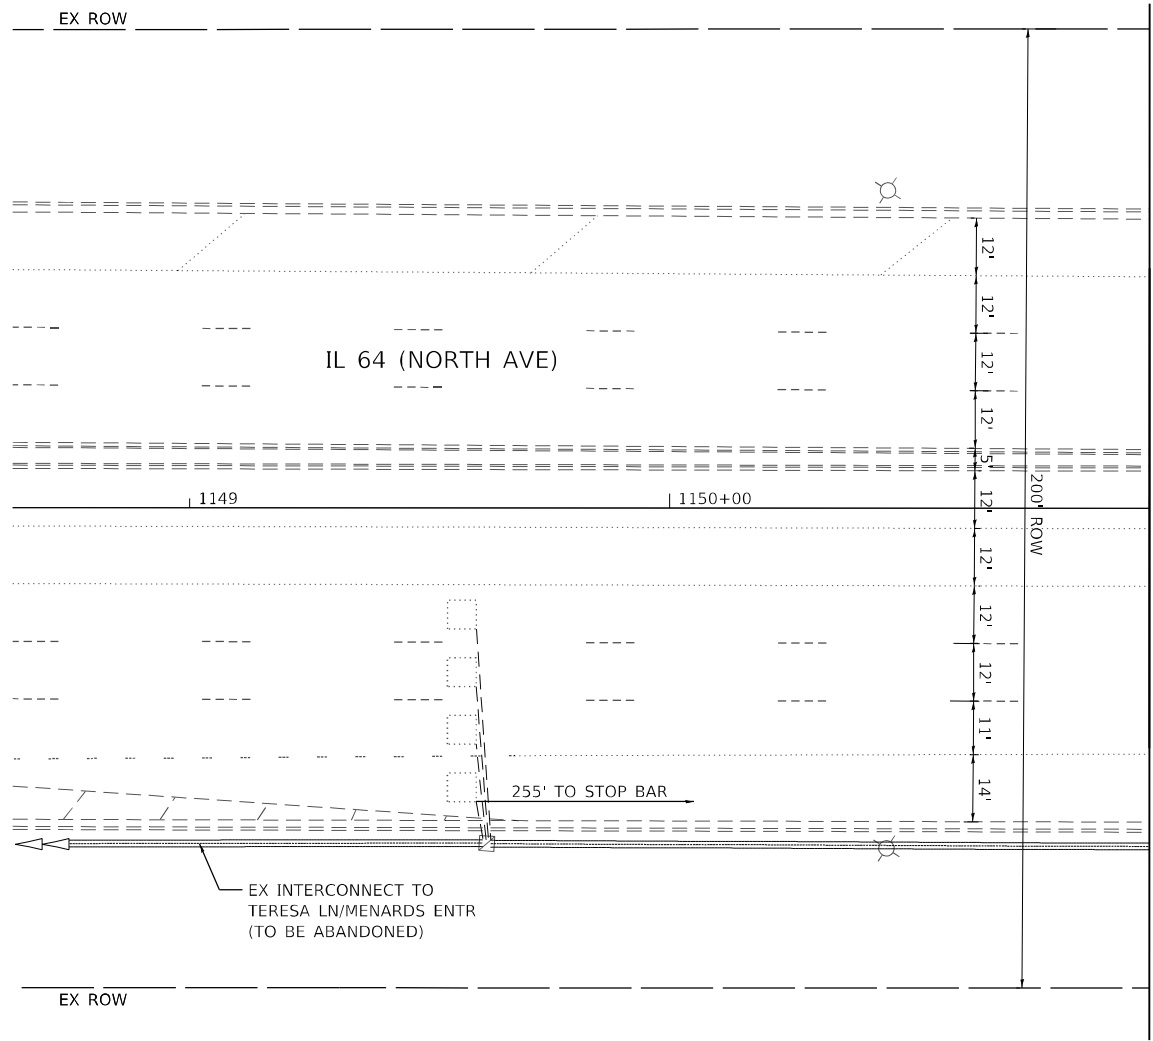

 PROTECTED PHASE
 PROTECTED/PERMITTED PHASE
 PEDESTRIAN PHASE
 OVERLAP

EXISTING AND PROPOSED EMERGENCY VEHICLE PREEMPTION SEQUENCE

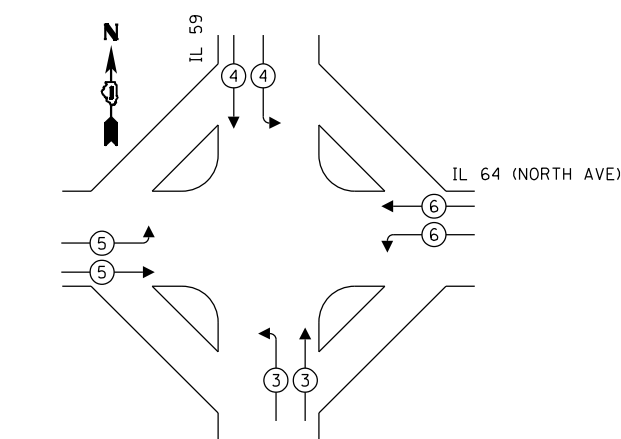

TYPE	QUANTITY	UNIT WATTAGE	TOTAL WATTAGE
SIGNAL HEAD 1 OR 3-SECTION	16	11	176
4-SECTION	-	14	-
5-SECTION	8	13	104
PROGRAMMABLE 3-SECTION	-	22	-
4-SECTION	-	32	-
5-SECTION	-	28	-
PEDESTRIAN SIGNAL	-	15	-
CONTROLLER	1	150	150
MASTER CONTROLLER	-	100	-
UPS	1	25	25
DETECTION RADAR OR VIDEO	-	20	-
BLANK-OUT SIGN	-	25	-
NETWORK SWITCH II OR III	1	35	35
CELLULAR MODEM	-	15	-
PTZ	1	75	75
TOTAL UPS SIZING			565
UPS CHARGING	1	225	225
BATTERY HEATER MAT	1	180	180
CABINET HEATER	1	200	200
FLASHER	-	15	-
LED STREET NAME SIGN	-	120	-
LUMINAIRE	-	240	-
TOTAL SERVICE WIRE SIZING			1170

TS 6355
IDOT TACTICS
FORMER EAGLE 5A

SIGN PANEL – TYPE 2

ALL DIMENSIONS ARE IN INCHES UNLESS OTHERWISE NOTED



DESIGN SERIES	AREA (SQ FT)	SIGN PANEL TYPE	SHEETING TYPE	QTY. REQUIRED
D	12.5	2	ZZ	2

SCHEDULE OF QUANTITIES

ITEM DESCRIPTION	UNIT	QUANTITY
SIGN PANEL - TYPE 2	SQ FT	25
UNDERGROUND CONDUIT, GALVANIZED STEEL, 2" DIA.	FOOT	5
MAINTENANCE OF EXISTING TRAFFIC SIGNAL INSTALLATION	EACH	1
ELECTRIC CABLE IN CONDUIT, SERVICE, NO. 6 2 C	FOOT	40
ELECTRIC CABLE IN CONDUIT, EQUIPMENT GROUNDING CONDUCTOR, NO. 6 1C	FOOT	40
CONCRETE FOUNDATION, TYPE A	FOOT	4
REMOVE EXISTING TRAFFIC SIGNAL EQUIPMENT	EACH	1
LED LAMP MODULE REPLACEMENT	EACH	80
SERVICE INSTALLATION, GROUND MOUNTED, METERED	EACH	1
LAYER II (DATALINK) SWITCH	EACH	1
TERMINATE FIBER IN CABINET	EACH	12
UPGRADE EXISTING CONTROLLER TO NTCIP SPECIAL	EACH	1
FIBER OPTIC INTERCONNECT CENTER, 48 PORT	EACH	1
LED SIGNAL FACE, LENS COVER	EACH	24

TS 6355
IDOT TACTICS
FORMER EAGLE 5A

Model: Default
File Name: p:\utp\pva\bartley.com\ktp\pva\01\Documents\01 Active Projects\MW\CL-S-160950\00 - IL 64\Phase II\2 Design\CAD\Plan Sheets\Sign\In\West Corridor Sign\BID\081714\rt-40_K4A.dgn

Kimley»Horn

© 2023 KIMLEY-HORN AND ASSOCIATES, INC.
4001 WHEATLAND ROAD, SUITE 600
WARREN, ILL. 60555
PHONE: 847.447.4555
WWW.KIMLEY-HORN.COM

USER NAME =	DESIGNED -	REVISED -
	DRAWN -	REVISED -
PLOT SCALE =	CHECKED -	REVISED -
PLOT DATE =	DATE -	REVISED -

STATE OF ILLINOIS
DEPARTMENT OF TRANSPORTATION

SCHEDULE OF QUANTITIES			
IL 64 (NORTH AVE) AND IL RTE 59			
SCALE: N.T.S.	SHEET	OF	SHEETS
STA.		TO STA.	

F.A.P. RTE.	SECTION	COUNTY	TOTAL SHEETS	SHEET NO.
307	2020-263-SUR,SW&TS	DUPAGE	529	141
CONTRACT NO. 62N33				
		ILLINOIS	FED. AID PROJECT	

NOTES

1. THE EXISTING TRAFFIC SIGNAL EQUIPMENT SHALL NOT BE REMOVED UNTIL THE PROPOSED TRAFFIC SIGNAL EQUIPMENT IS FULLY OPERATIONAL OR AS DIRECTED BY THE ENGINEER.
2. ALL EXISTING TRAFFIC SIGNAL CABLE NO LONGER REQUIRED SHALL BE REMOVED.


REMOVAL NOTES

THE FOLLOWING ITEMS SHALL BE REMOVED BY THE CONTRACTOR AND SHALL BE DISPOSED OF BY THEM OUTSIDE THE RIGHT-OF-WAY AT THEIR EXPENSE. THE SALVAGE VALUE OF THE REMOVED EQUIPMENT SHALL BE REFLECTED IN CONTRACT BID PRICE.

- 16 EACH 3-SECTION SIGNAL HEAD
4 EACH 5-SECTION SIGNAL HEAD
10 EACH TRAFFIC SIGNAL BACKPLATES
2 EACH MAST ARM AND ASSEMBLY AND POLE
4 EACH TRAFFIC SIGNAL POST
3 EACH STREET NAME SIGN PANEL
1 EACH CONTROLLER (M41)

THE FOLLOWING ITEMS SHALL BE REMOVED BY THE CONTRACTOR, SHALL REMAIN THE PROPERTY OF THE ILLINOIS DEPARTMENT OF TRANSPORTATION, AND SHALL BE DELIVERED BY THE CONTRACTOR TO IDOT'S TRAFFIC SIGNAL MAINTENANCE CONTRACTOR'S MAIN FACILITY.

- 1 EACH VIDEO VEHICLE DETECTION SYSTEM

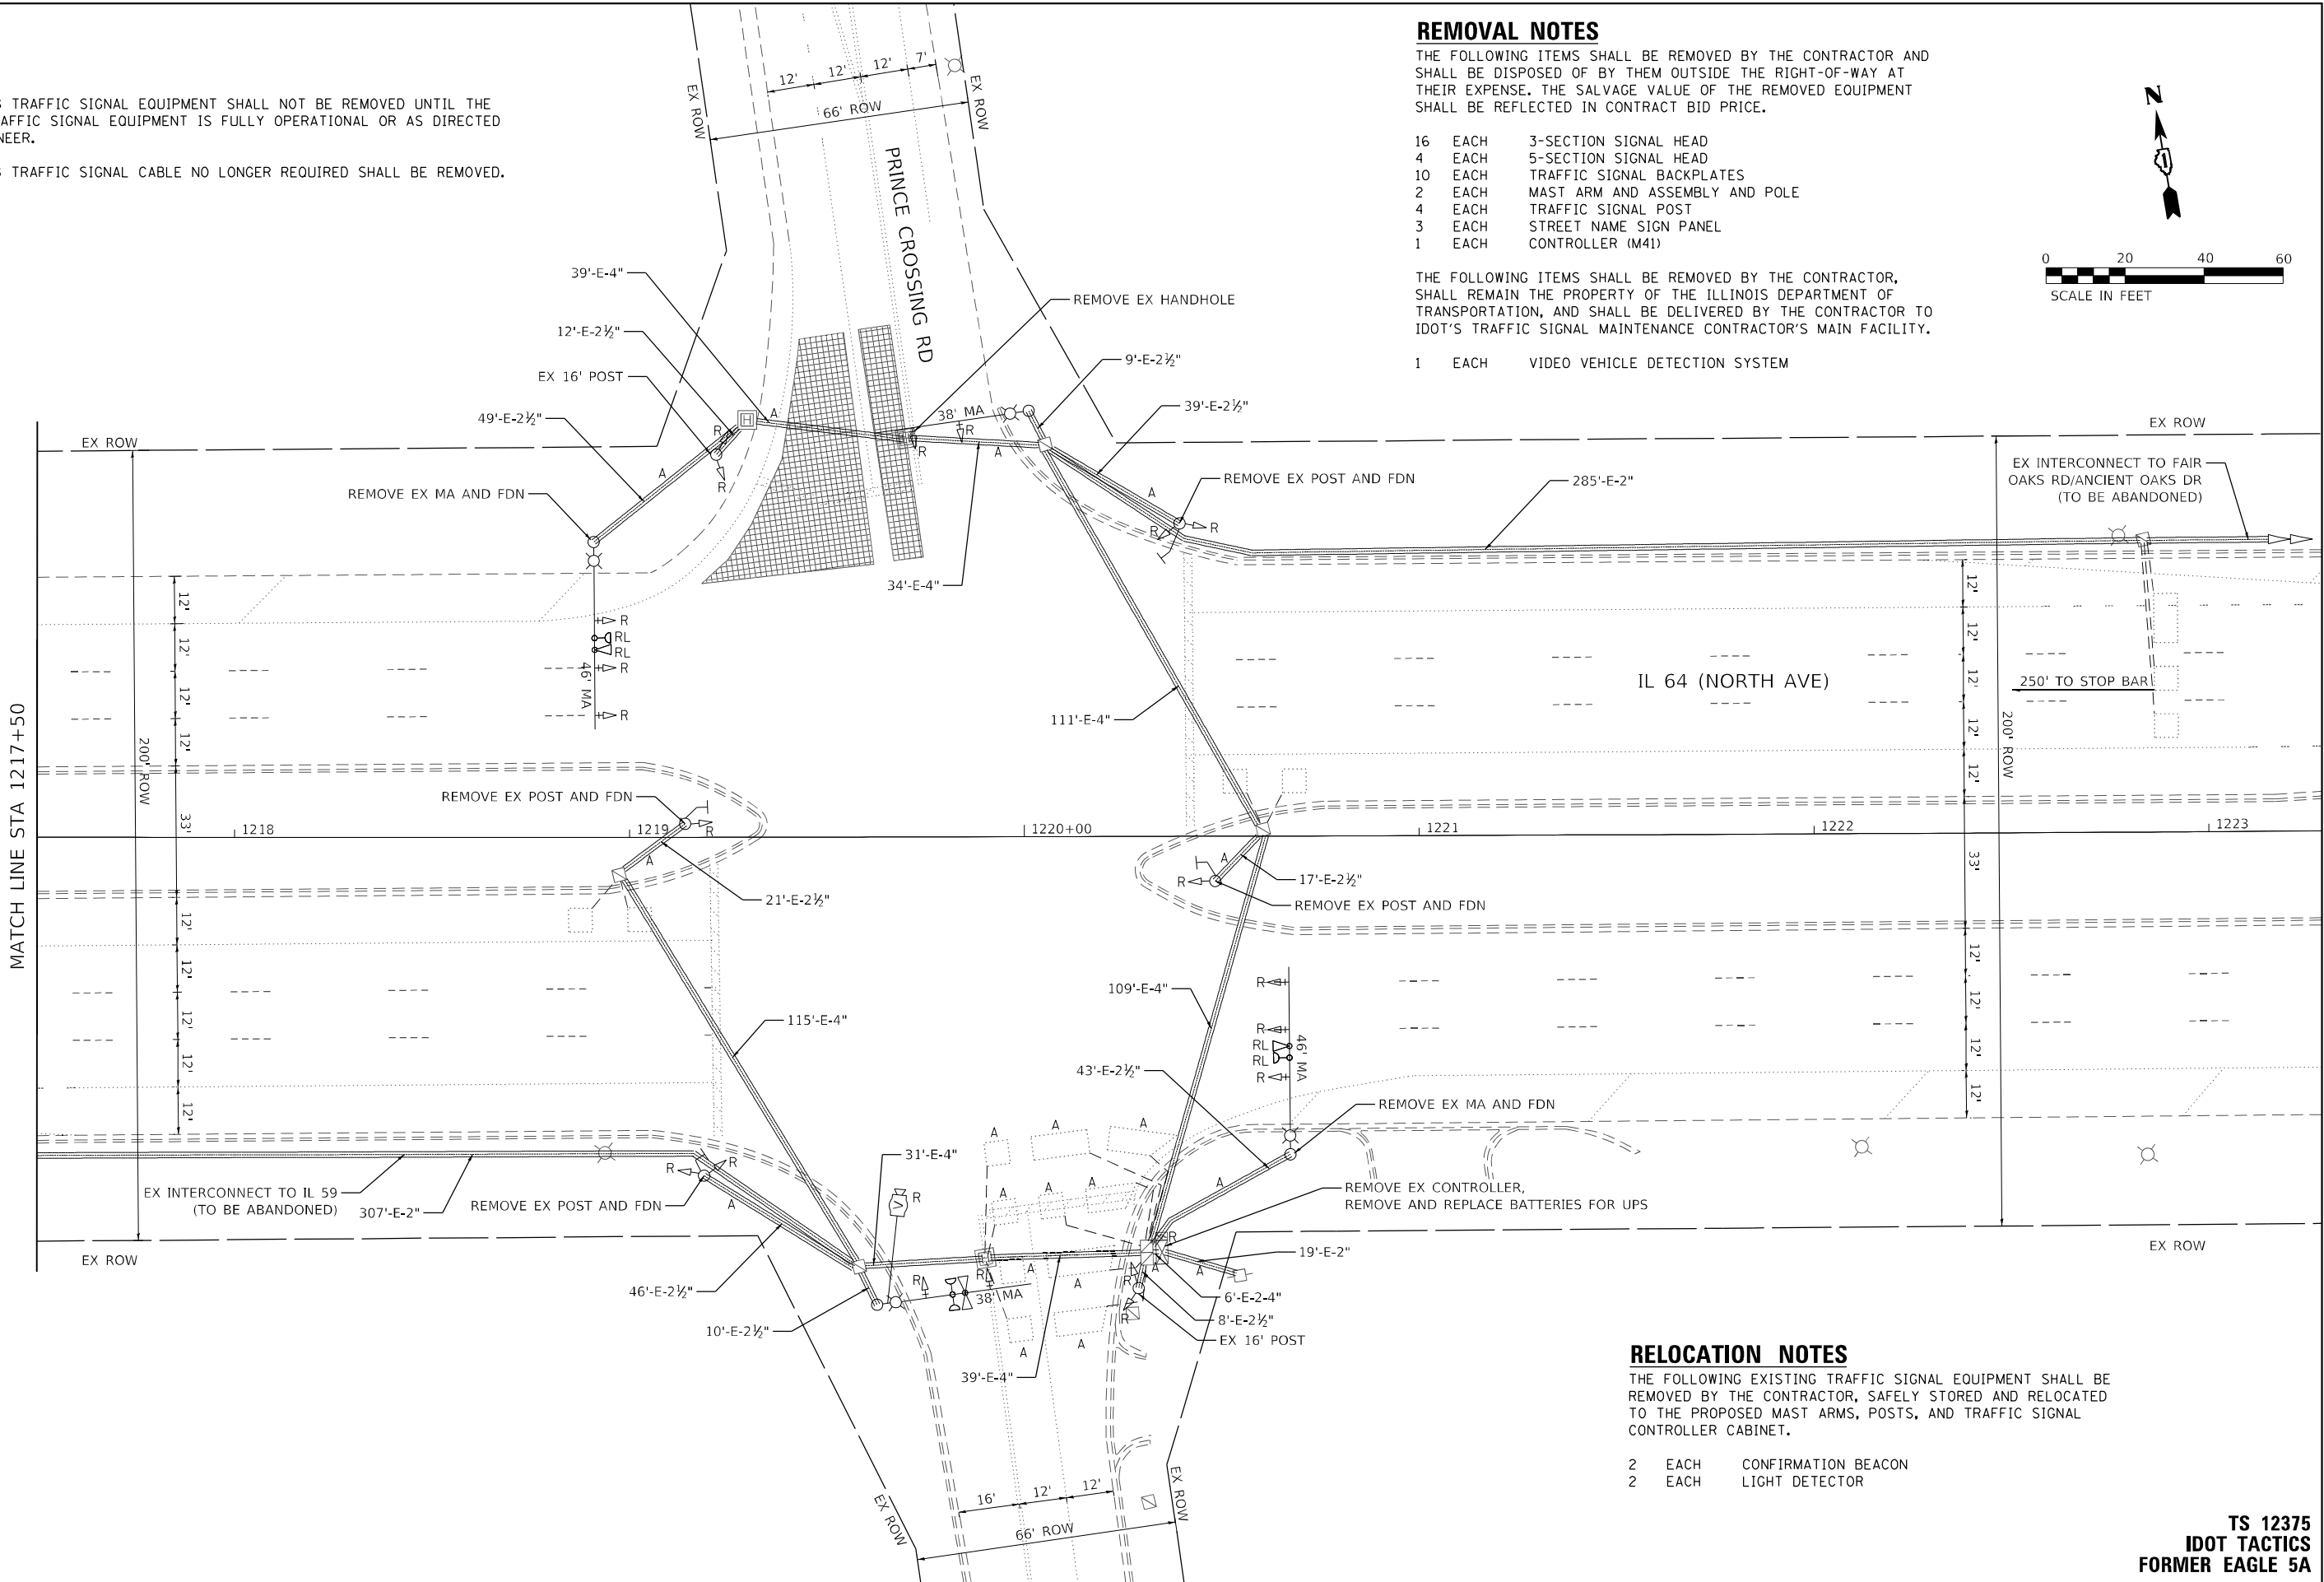

RELOCATION NOTES

THE FOLLOWING EXISTING TRAFFIC SIGNAL EQUIPMENT SHALL BE REMOVED BY THE CONTRACTOR, SAFELY STORED AND RELOCATED TO THE PROPOSED MAST ARMS, POSTS, AND TRAFFIC SIGNAL CONTROLLER CABINET.

- 2 EACH CONFIRMATION BEACON
2 EACH LIGHT DETECTOR

TS 12375
IDOT TACTICS
FORMER EAGLE 5A

KimleyHorn

© 2023 KIMLEY-HORN AND ASSOCIATES, INC.
4001 WILMINGTON ROAD, SUITE 600
WARREN, IL 60555
PHONE: (847) 455-4555
WWW.KH.COM



USER NAME =	DESIGNED -	REVISED -
	DRAWN -	REVISED -
PLOT SCALE =	CHECKED -	REVISED -
PLOT DATE =	DATE -	REVISED -

STATE OF ILLINOIS
DEPARTMENT OF TRANSPORTATION

TRAFFIC SIGNAL EQUIPMENT REMOVAL PLAN
IL 64 (NORTH AVE) AND PRINCE CROSSING RD

SCALE: 1" = 20' SHEET OF SHEETS STA. TO STA.

F.A.P. RTE.	SECTION	COUNTY	TOTAL SHEETS	SHEET NO.
307	2020-263-SUR, SW&TS	DUPAGE	529	142
CONTRACT NO. 62N33				
ILLINOIS FED. AID PROJECT				

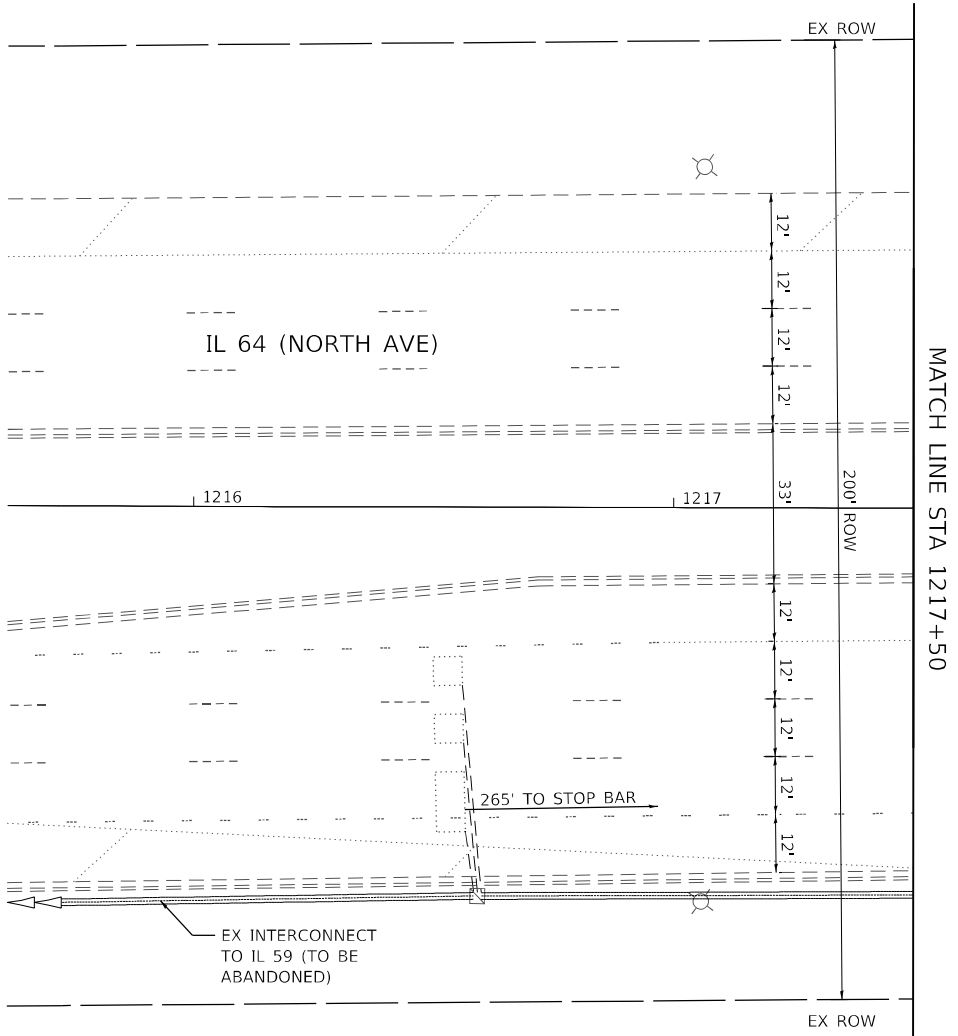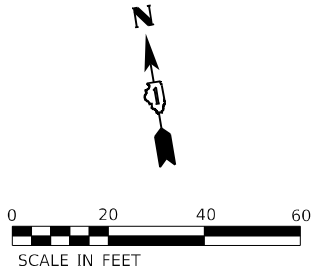

MODEL: Default
FILE NAME: p:\sub-pw\bartley.com\k-h-pw-d1\Documents\01 Active Projects\MW\CHS-168950\00 - IL 64\Phase II\2 Design\CAD\Plan Sheets\Signal\West Corridor Signal\01081714-IL-64-2_KH.dgn



USER NAME =	DESIGNED -	REVISED -
	DRAWN -	REVISED -
PLOT SCALE =	CHECKED -	REVISED -
PLOT DATE =	DATE -	REVISED -



STATE OF ILLINOIS
DEPARTMENT OF TRANSPORTATION

TRAFFIC SIGNAL EQUIPMENT REMOVAL PLAN
IL 64 (NORTH AVE) AND PRINCE CROSSING RD

SCALE: 1" = 20' SHEET OF SHEETS STA. TO STA.

F.A.P. RTE.	SECTION	COUNTY	TOTAL SHEETS	SHEET NO.
307	2020-263-SUR, SW&TS	DUPAGE	529	143
CONTRACT NO. 62N33				
		ILLINOIS	FED. AID PROJECT	

TS 12375
IDOT TACTICS
FORMER EAGLE 5A

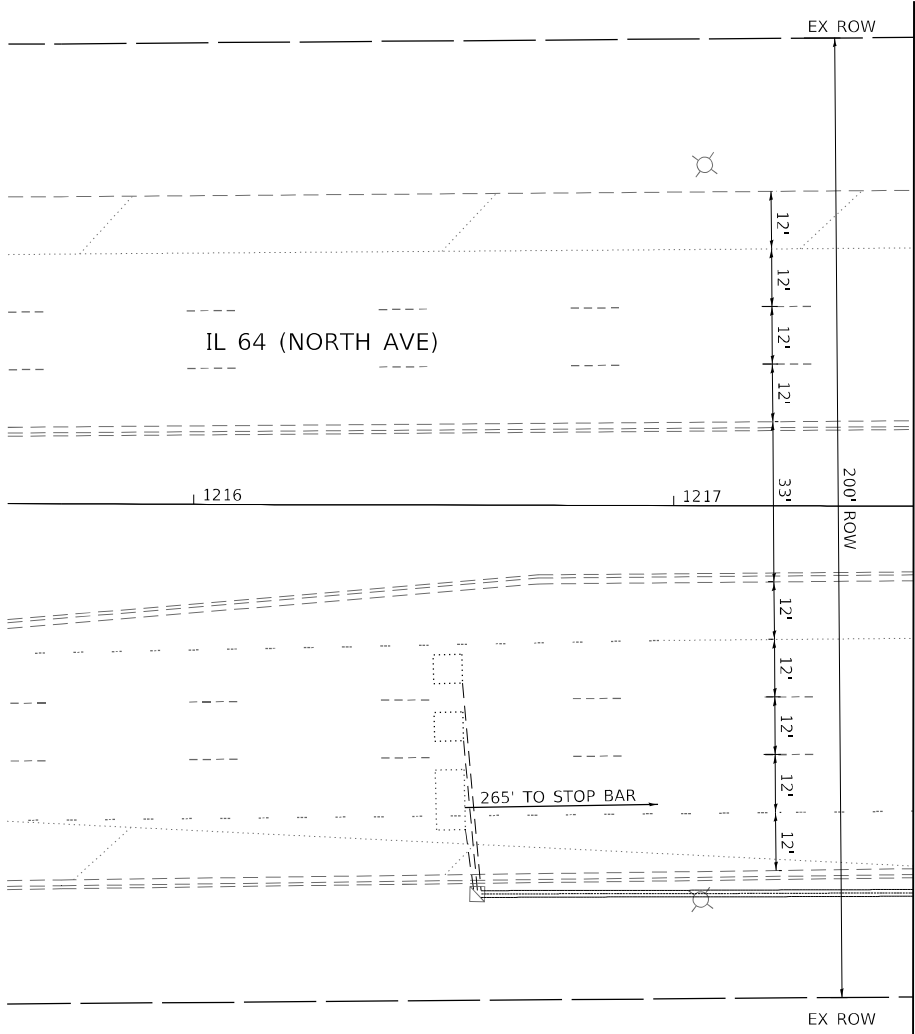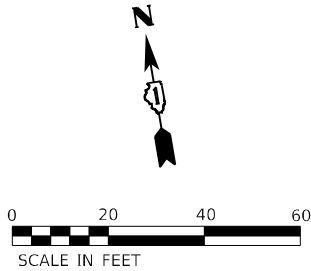

MODEL: Default
FILE NAME: p:\sub-pw\bartley.com\k-h-pw-d\Documents\01 Active Projects\MW\CHS-16895\100 - IL 64\Phase II\2 Design\CAD\Plan Sheets\Signal\West Corridor Signal\01081714-IL-64-K4A.dgn



USER NAME	=	DESIGNED	-	REVISED	-
		DRAWN	-	REVISED	-
PLOT SCALE	=	CHECKED	-	REVISED	-
PLOT DATE	=	DATE	-	REVISED	-

STATE OF ILLINOIS
DEPARTMENT OF TRANSPORTATION


TRAFFIC SIGNAL MODERNIZATION PLAN
IL 64 (NORTH AVE) AND PRINCE CROSSING RD

SCALE: 1" = 20' SHEET OF SHEETS STA. TO STA.


F.A.P. RTE.	SECTION	COUNTY	TOTAL SHEETS	SHEET NO.
307	2020-263-SUR, SW&TS	DUPAGE	529	145
CONTRACT NO. 62N33				
		ILLINOIS	FED. AID PROJECT	

TS 12375
IDOT TACTICS
FORMER EAGLE 5A

EXISTING CONTROLLER SEQUENCE

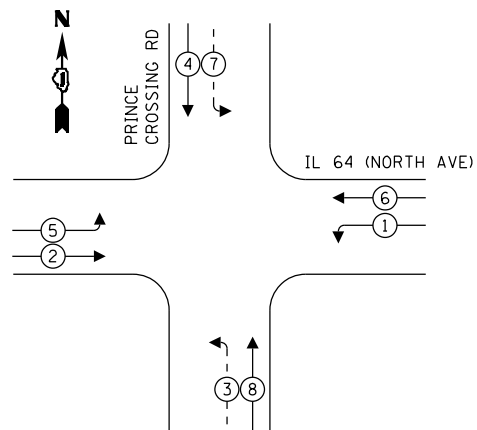


PROPOSED CONTROLLER SEQUENCE

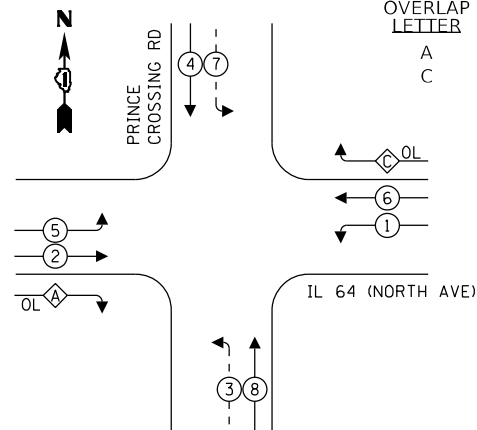

OVERLAP LETTER		PERMISSIVE PHASE		PROTECTED PHASE
A	=	2	+	3
C	=	6	+	7

EXISTING AND PROPOSED EMERGENCY VEHICLE PREEMPTION SEQUENCE

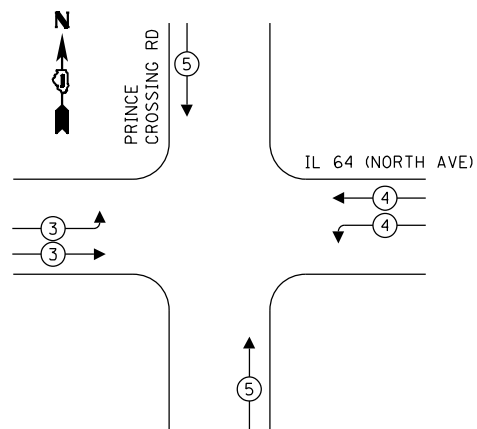

LEGEND:

-  PROTECTED PHASE
 PROTECTED/PERMITTED PHASE
 PEDESTRIAN PHASE
 OVERLAP

TRAFFIC SIGNAL ELECTRICAL SERVICE REQUIREMENTS

TYPE	QUANTITY	UNIT WATTAGE	TOTAL WATTAGE
SIGNAL HEAD 1 OR 3-SECTION	14	11	154
4-SECTION	-	14	-
5-SECTION	8	13	104
PROGRAMMABLE 3-SECTION	-	22	-
4-SECTION	-	32	-
5-SECTION	-	28	-
PEDESTRIAN SIGNAL	-	15	-
CONTROLLER	1	150	150
MASTER CONTROLLER	-	100	-
UPS	1	25	25
DETECTION VIDEO	2	20	40
BLANK-OUT SIGN	-	25	-
NETWORK SWITCH LAYER II OR III	1	35	35
CELLULAR MODEM	-	15	-
PTZ	1	75	75
TOTAL UPS SIZING			583
UPS CHARGING	1	225	225
BATTERY HEATER MAT	1	180	180
CABINET HEATER	1	200	200
FLASHER	-	15	-
LED STREET NAME SIGN	-	120	-
LUMINAIRE	-	240	-
TOTAL SERVICE WIRE SIZING			1188

NOTES


1. EXISTING CABLE SLACK SHALL BE USED TO INSTALL PROPOSED SIGNAL HEADS AND EVP DETECTOR AT THEIR NEW LOCATION ALONG THE EXISTING MAST ARM.

ENERGY COSTS TO:
ILLINOIS DEPARTMENT OF TRANSPORTATION
201 W CENTER CT
SCHAUMBURG, IL 60196

ENERGY SUPPLY: COMPANY: COMED
PHONE: (866) 639-3532
ACCOUNT NUMBER: 73470-49055

LEGEND:

* = ROADWAY LIGHTING CABLE

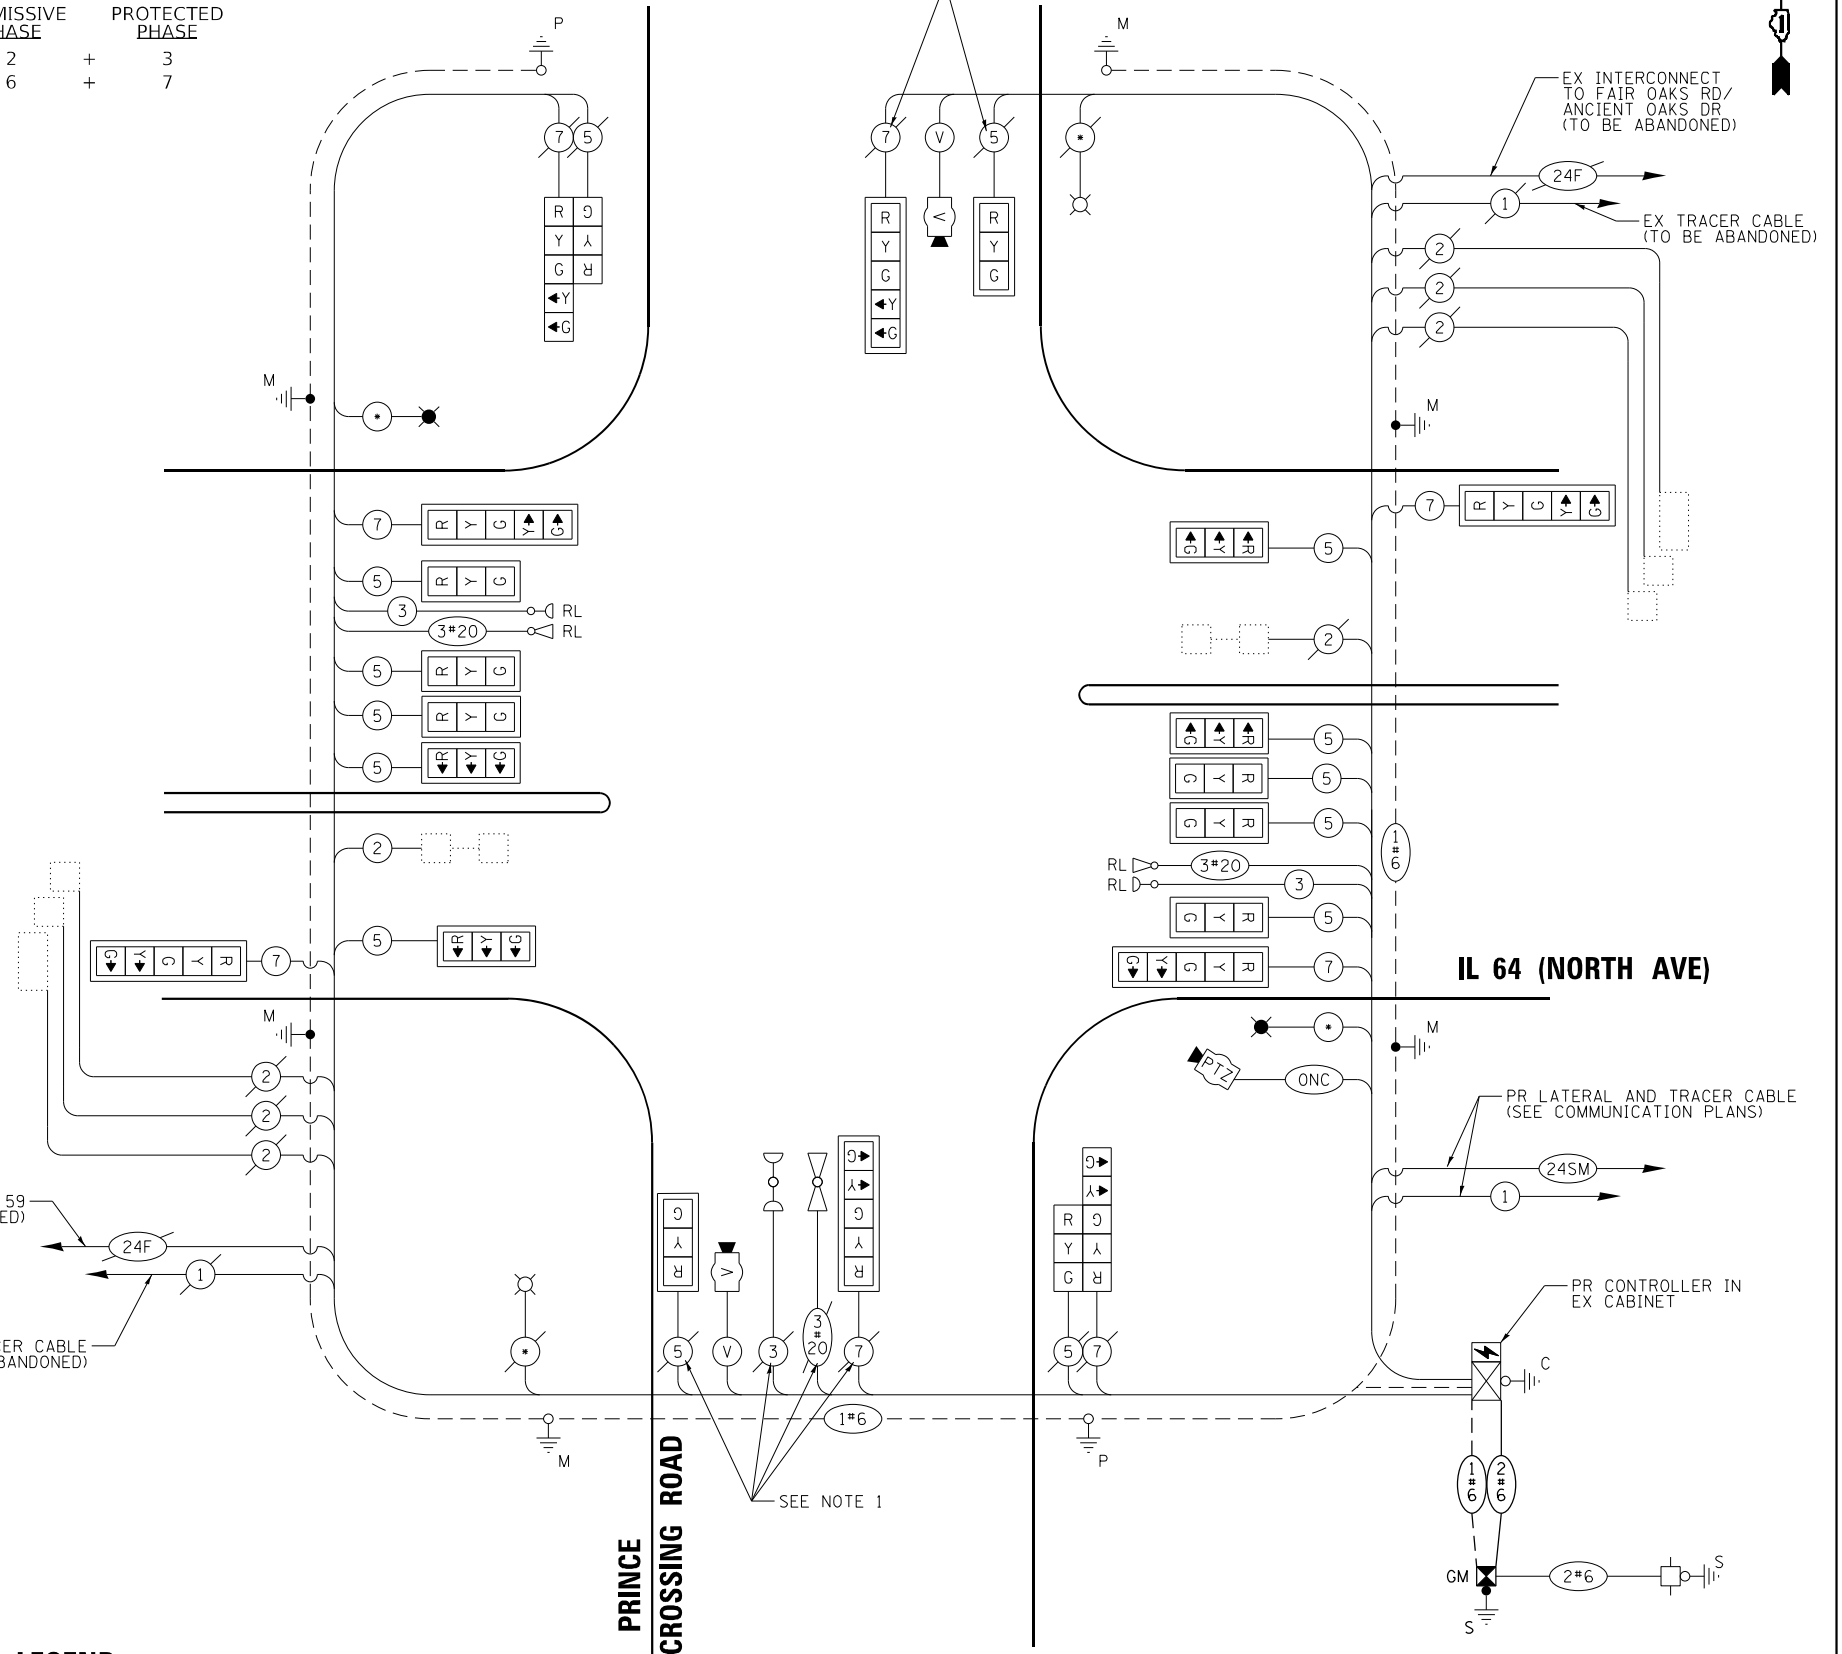

CABLE PLAN


(NOT TO SCALE)

TS 12375
IDOT TACTICS
FORMER EAGLE 5A

[illegible]

SIGN PANEL – TYPE 2

ALL DIMENSIONS ARE IN INCHES UNLESS OTHERWISE NOTED

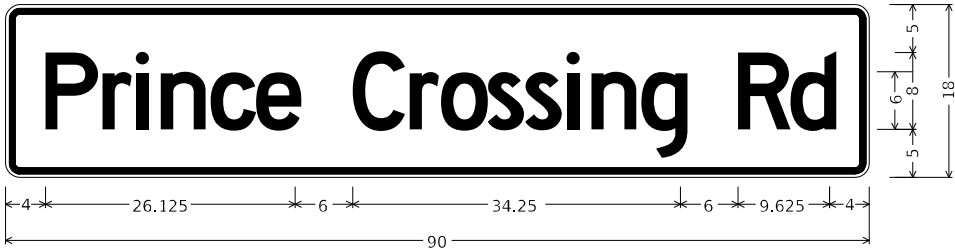

DESIGN SERIES	AREA (SQ FT)	SIGN PANEL TYPE	SHEETING TYPE	QTY. REQUIRED
C	11.25	2	ZZ	2



DESIGN SERIES	AREA (SQ FT)	SIGN PANEL TYPE	SHEETING TYPE	QTY. REQUIRED
D	12.5	2	ZZ	2

SCHEDULE OF QUANTITIES

ITEM DESCRIPTION	UNIT	QUANTITY
SIGN PANEL - TYPE 2	SQ FT	47.5
UNDERGROUND CONDUIT, GALVANIZED STEEL, 2" DIA.	FOOT	5
UNDERGROUND CONDUIT, GALVANIZED STEEL, 3" DIA.	FOOT	172
UNDERGROUND CONDUIT, GALVANIZED STEEL, 4" DIA.	FOOT	410
DOUBLE HANDHOLE	EACH	1
MAINTENANCE OF EXISTING TRAFFIC SIGNAL INSTALLATION	EACH	1
ELECTRIC CABLE IN CONDUIT, SIGNAL NO. 14 3C	FOOT	661
ELECTRIC CABLE IN CONDUIT, SIGNAL NO. 14 5C	FOOT	3215
ELECTRIC CABLE IN CONDUIT, SIGNAL NO. 14 7C	FOOT	1232
ELECTRIC CABLE IN CONDUIT, SERVICE, NO. 6 2 C	FOOT	31
ELECTRIC CABLE IN CONDUIT, EQUIPMENT GROUNDING CONDUCTOR, NO. 6 1C	FOOT	613
STEEL MAST ARM ASSEMBLY AND POLE, 24 FT.	EACH	1
STEEL MAST ARM ASSEMBLY AND POLE, 32 FT.	EACH	1
STEEL COMBINATION MAST ARM ASSEMBLY AND POLE 64 FT.	EACH	1
STEEL COMBINATION MAST ARM ASSEMBLY AND POLE 66 FT.	EACH	1
CONCRETE FOUNDATION, TYPE A	FOOT	4
CONCRETE FOUNDATION, TYPE E 30-INCH DIAMETER	FOOT	10
CONCRETE FOUNDATION, TYPE E 36-INCH DIAMETER	FOOT	13.5
CONCRETE FOUNDATION, TYPE E 42-INCH DIAMETER	FOOT	46
DRILL EXISTING HANDHOLE	EACH	9
SIGNAL HEAD, LED, 1-FACE, 3-SECTION, MAST-ARM MOUNTED	EACH	12
SIGNAL HEAD, LED, 1-FACE, 3-SECTION, BRACKET MOUNTED	EACH	2
SIGNAL HEAD, LED, 1-FACE, 5-SECTION, BRACKET MOUNTED	EACH	2
SIGNAL HEAD, LED, 1-FACE, 5-SECTION, MAST-ARM MOUNTED	EACH	6
TRAFFIC SIGNAL BACKPLATE, LOUVERED, FORMED PLASTIC	EACH	18
* RELOCATE EXISTING EMERGENCY VEHICLE PRIORITY SYSTEM, DETECTOR UNIT	EACH	2
REMOVE EXISTING TRAFFIC SIGNAL EQUIPMENT	EACH	1
REMOVE EXISTING HANDHOLE	EACH	1
REMOVE EXISTING CONCRETE FOUNDATION	EACH	6
CLOSED CIRCUIT TELEVISION DOME CAMERA, HD	EACH	1
* EMERGENCY VEHICLE PRIORITY SYSTEM LINE SENSOR CABLE, NO. 20 3/C	FOOT	660
OUTDOOR RATED NETWORK CABLE	FOOT	159
SERVICE INSTALLATION, GROUND MOUNTED, METERED	EACH	1
REMOTE CONTROLLED VIDEO SYSTEM	EACH	1
LAYER II (DATALINK) SWITCH	EACH	1
TERMINATE FIBER IN CABINET	EACH	12
TACTICS LICENSE EXPANSION	EACH	1
FULL-ACTUATED CONTROLLER IN EXISTING CABINET	EACH	1
REMOVE AND REPLACE BATTERIES FOR UNINTERUPTABLE POWER SUPPLY, EXTENDED	EACH	1
FIBER OPTIC INTERCONNECT CENTER, 48 PORT	EACH	1
LED SIGNAL FACE, LENS COVER	EACH	22
VIDEO VEHICLE DETECTION SYSTEM, SINGLE APPROACH	EACH	2
CAMERA MOUNTING ASSEMBLY	EACH	1

* - 100% COST TO THE CITY OF WEST CHICAGO

TS 12375
IDOT TACTICS
FORMER EAGLE 5A

MODEL: Default
FILE: Kimley-Horn\ut-pw-bentley.com\khp-gp-d11\Documents\01 Active Projects\WW-CIS-68959\00 - IL 64\Phase II\2 Design\CAD\Plan_Sheets\Sign\MainWest_Corridor_Signals\ID 108171-IL-Rte-46_KH.dgn



© 2021 KIMLEY-HORN AND ASSOCIATES, INC.
4001 KIMBLE D ROAD, SUITE 600
WARREN, IL 6. 0585
PHONE: 815.477.4555
WWW.KIMLEY-HORN.COM

USER NAME =	DESIGNED -	REVISED -
	DRAWN -	REVISED -
PLOT SCALE =	CHECKED -	REVISED -
PLOT DATE =	DATE -	REVISED -

STATE OF ILLINOIS
DEPARTMENT OF TRANSPORTATION

MAST ARM MOUNTED STREET NAME SIGNS AND
SCHEDULE OF QUANTITIES
IL 64 (NORTH AVE) AND PRINCE CROSSING RD

SCALE: N.T.S. SHEET OF SHEETS STA. TO STA.

F.A.P. RTE.	SECTION	COUNTY	TOTAL SHEETS	SHEET NO.
307	2020-263-SUR,SW&TS	DUPAGE	529	147
CONTRACT NO. 62N33				
ILLINOIS FED. AID PROJECT				

REMOVAL NOTES

THE FOLLOWING ITEMS SHALL BE REMOVED BY THE CONTRACTOR AND SHALL BE DISPOSED OF BY THEM OUTSIDE THE RIGHT-OF-WAY AT THEIR EXPENSE. THE SALVAGE VALUE OF THE REMOVED EQUIPMENT SHALL BE REFLECTED IN CONTRACT BID PRICE.



- 18 EACH SIGNAL HEAD, 1 FACE, 3 SECTION
- 10 EACH TRAFFIC SIGNAL BACKPLATE
- 3 EACH COMBINATION MAST ARM ASSEMBLY AND POLE
- 3 EACH TRAFFIC SIGNAL POST
- 4 EACH STREET NAME SIGN PANEL
- 1 EACH CONTROLLER (M41)
- 1 EACH GROUND MOUNTED SERVICE

THE FOLLOWING ITEMS SHALL BE REMOVED BY THE CONTRACTOR, SHALL REMAIN THE PROPERTY OF THE ILLINIS DEPARTMENT OF TRANSPORTATION, AND SHALL BE DELIVERED BY THE CONTRACTOR TO IDOT'S TRAFFIC SIGNAL MAINTENANCE CONTRACTOR'S MAIN FACILITY.

- 1 EACH VIDEO VEHICLE DETECTION SYSTEM (COMPLETE INTERSECTION)

NOTES

- 1. THE EXISTING TRAFFIC SIGNAL EQUIPMENT SHALL NOT BE REMOVED UNTIL THE PROPOSED TRAFFIC SIGNAL EQUIPMENT IS FULLY OPERATIONAL OR AS DIRECTED BY THE ENGINEER.
- 2. ALL EXISTING TRAFFIC SIGNAL CABLE NO LONGER REQUIRED SHALL BE REMOVED.
- 3. THE ELECTRIC METER SHALL BE RELOCATED FROM THE EXISTING TRAFFIC SIGNAL CABINET TO THE PROPOSED GROUND MOUNTED METERED SERVICE CABINET.

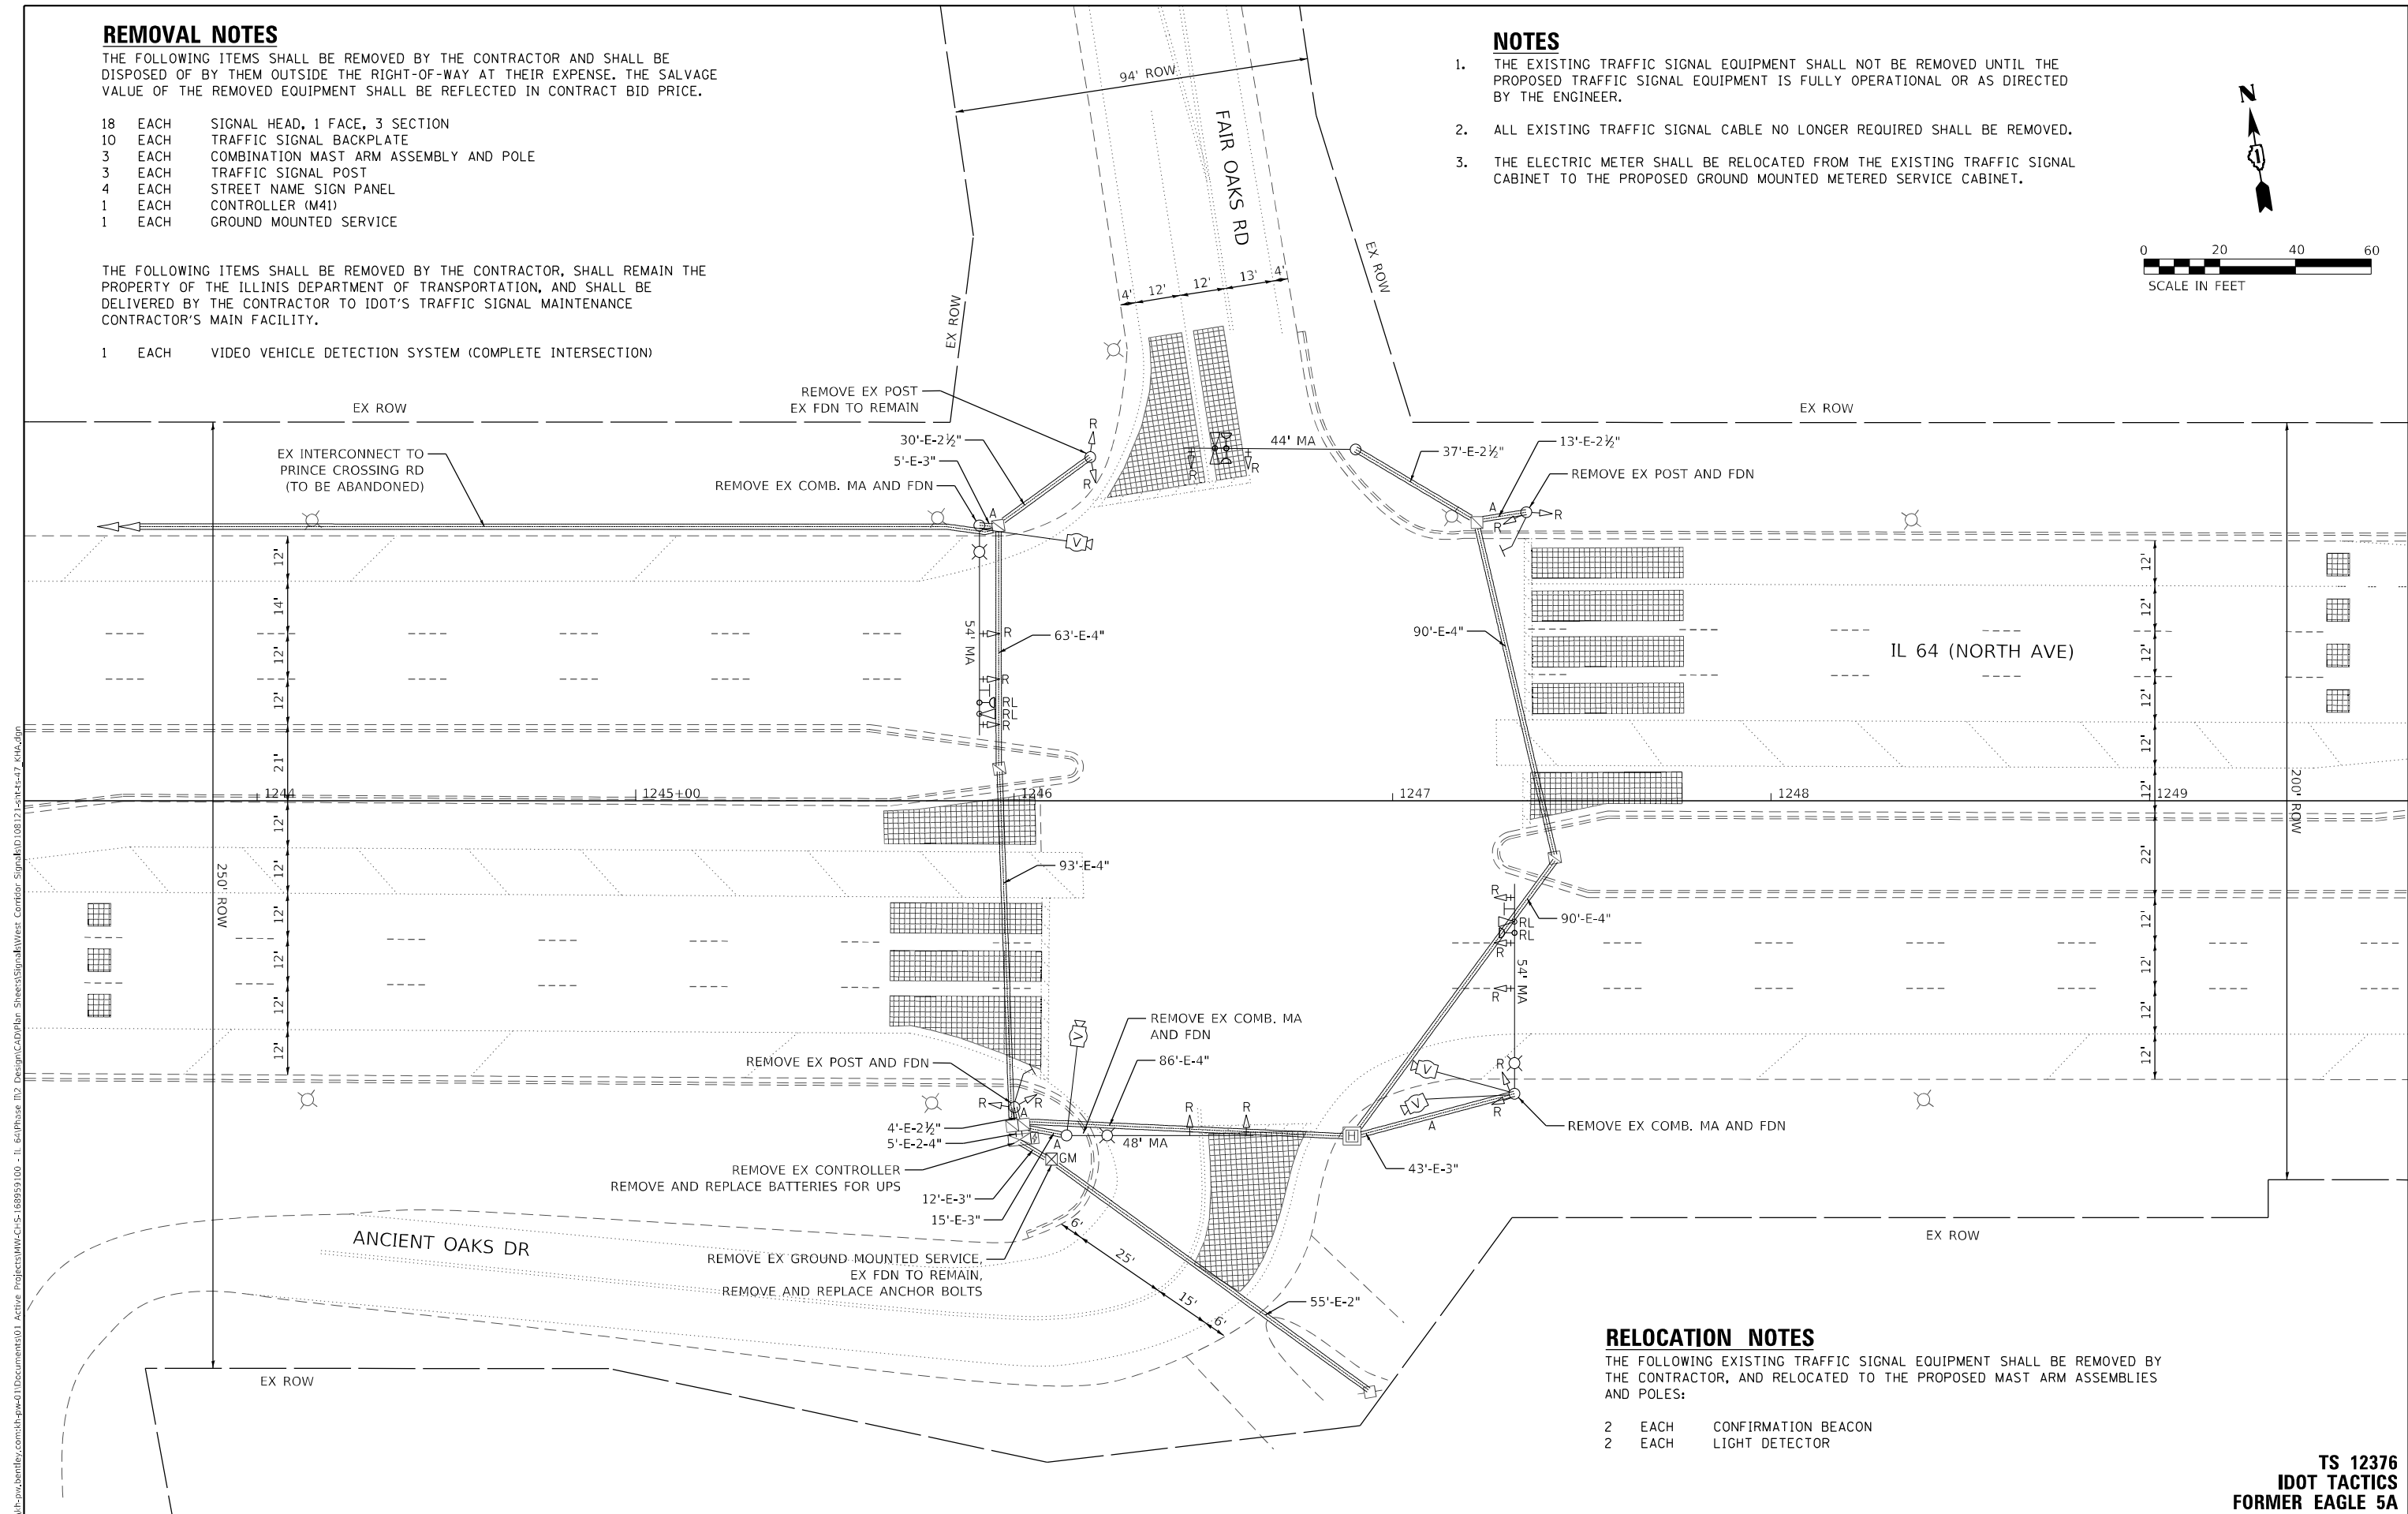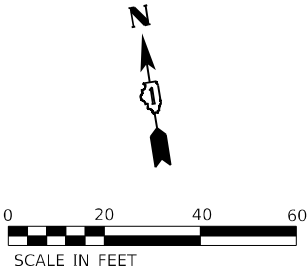

RELOCATION NOTES

THE FOLLOWING EXISTING TRAFFIC SIGNAL EQUIPMENT SHALL BE REMOVED BY THE CONTRACTOR, AND RELOCATED TO THE PROPOSED MAST ARM ASSEMBLIES AND POLES:



- 2 EACH CONFIRMATION BEACON
- 2 EACH LIGHT DETECTOR

TS 12376
IDOT TACTICS
FORMER EAGLE 5A

A

LEFT ON
GREEN
ARROW
ONLY

R10-5
30" X 36"
(4 EACH REQUIRED)

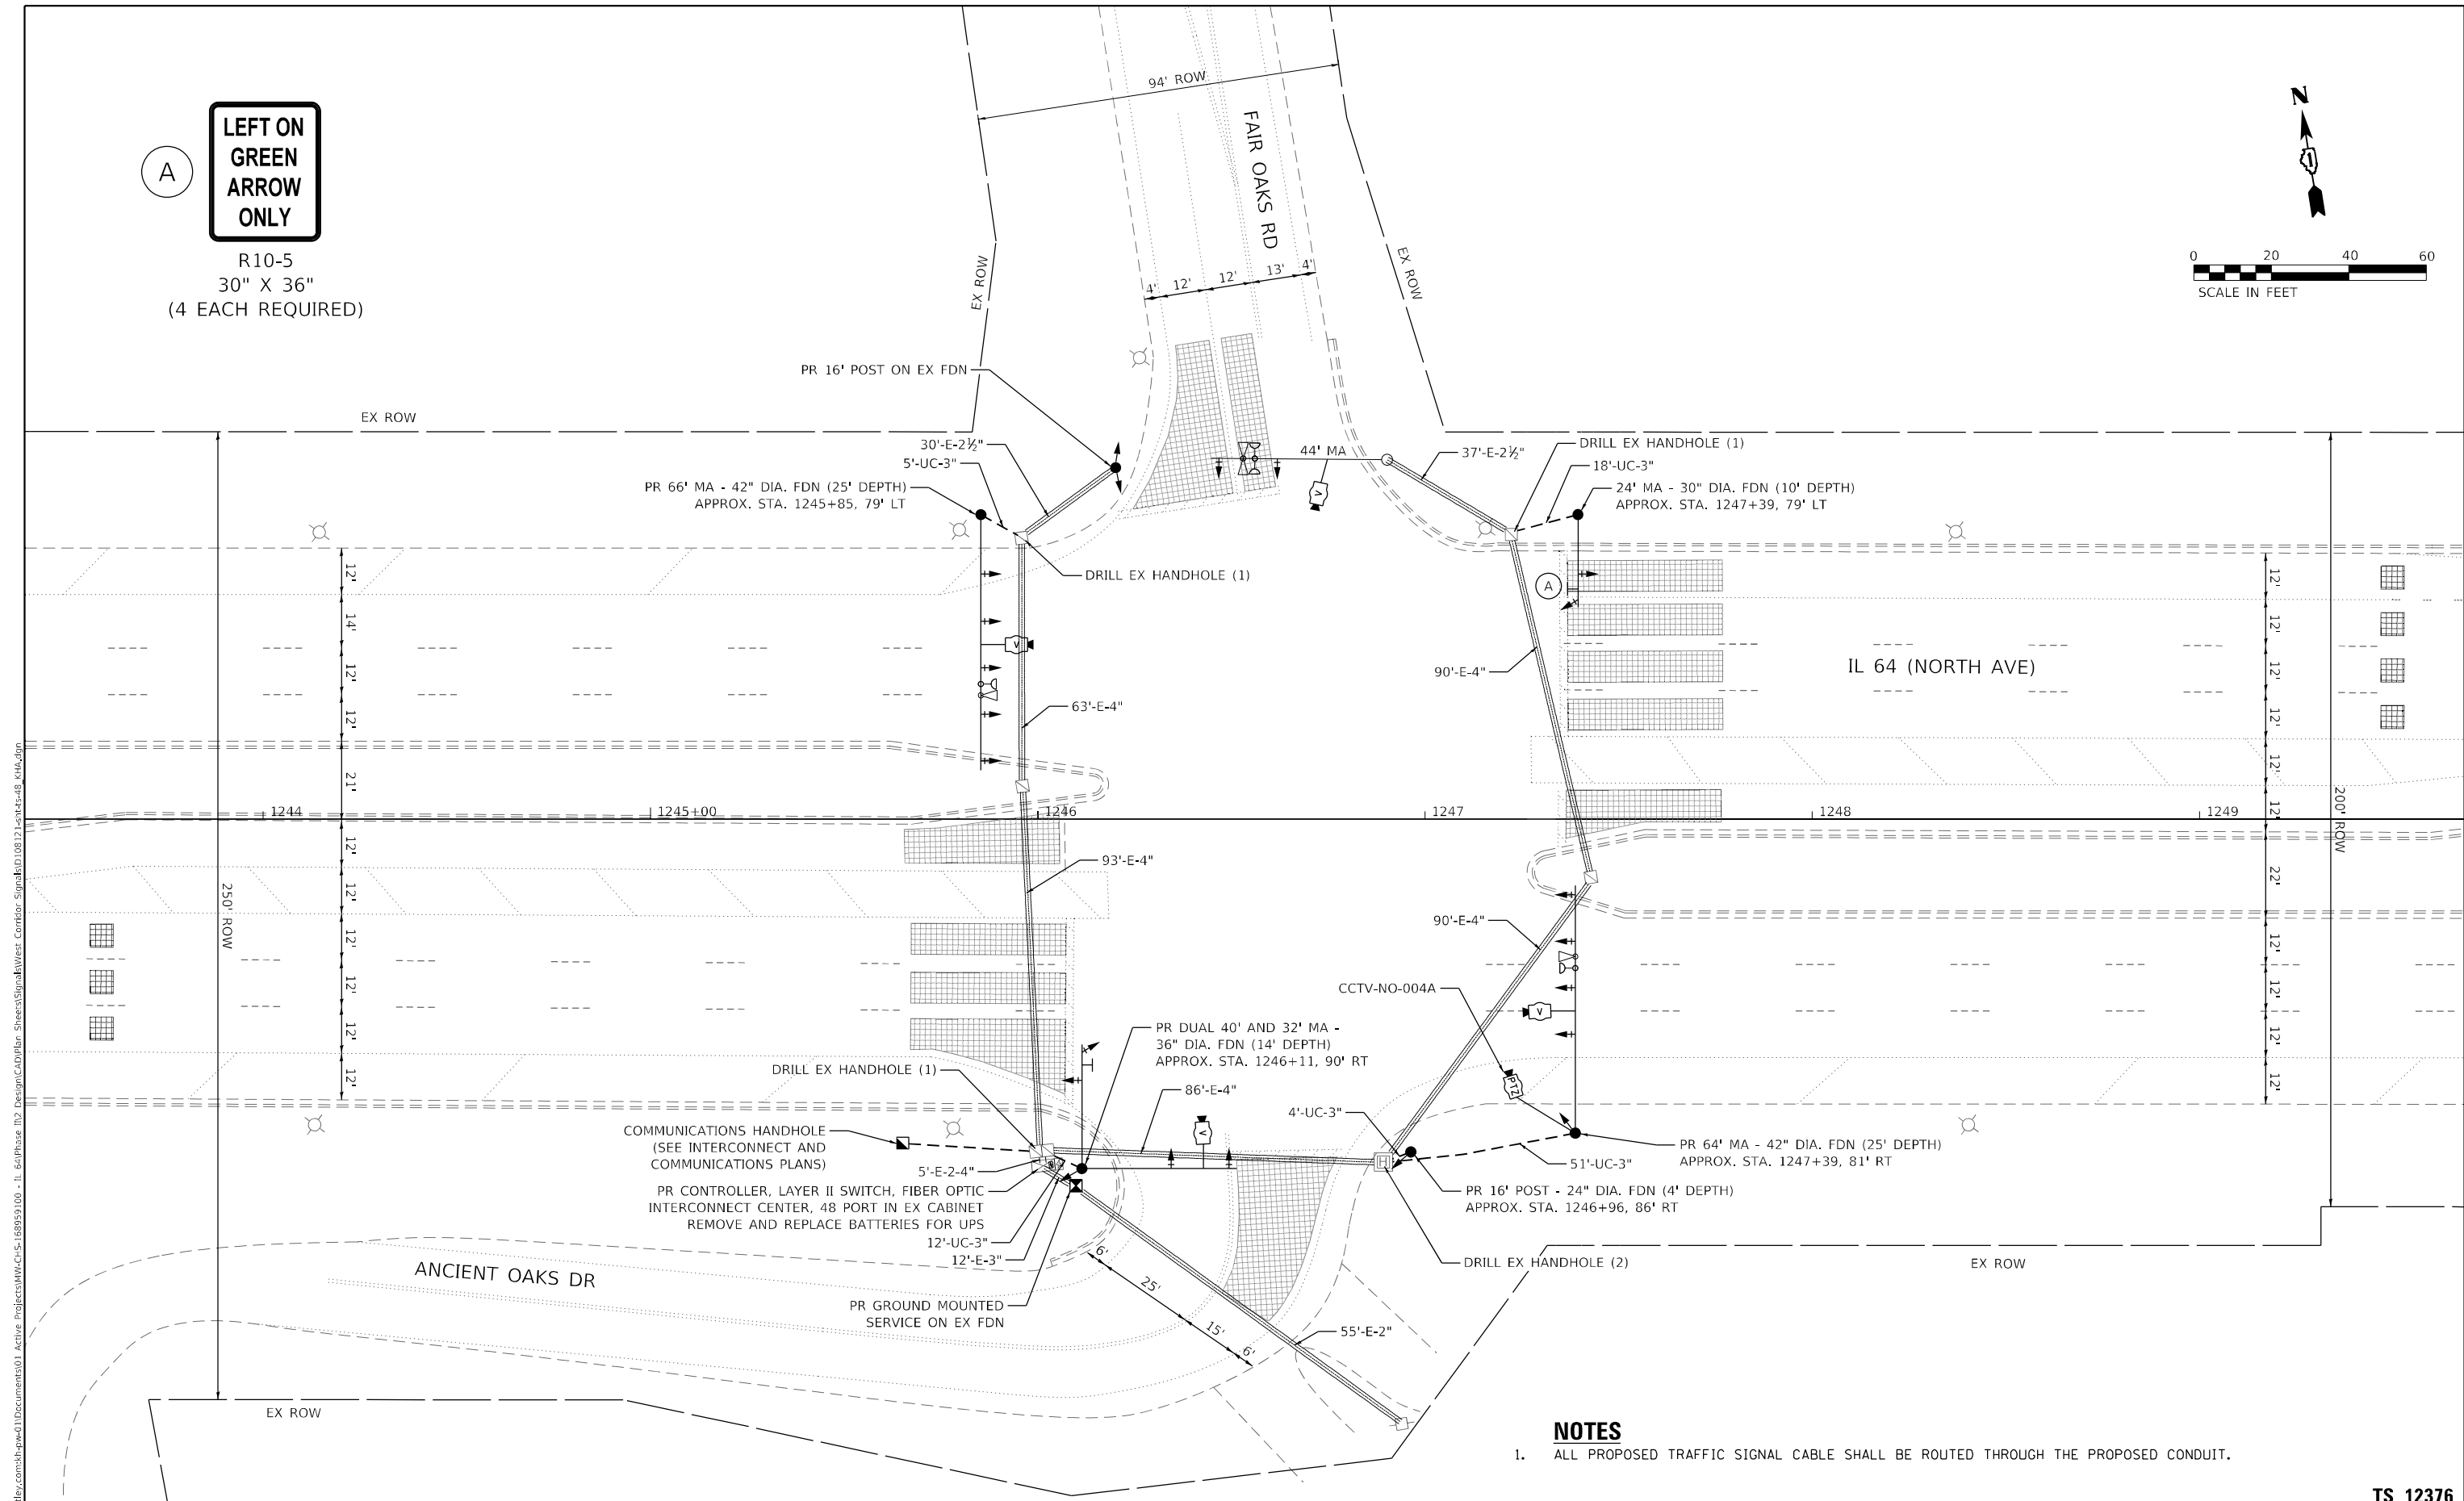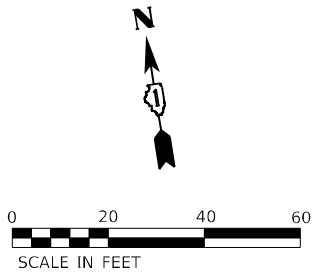

NOTES

1. ALL PROPOSED TRAFFIC SIGNAL CABLE SHALL BE ROUTED THROUGH THE PROPOSED CONDUIT.

TS 12376
IDOT TACTICS
FORMER EAGLE 5A

Kimley»Horn

© 2021 KIMLEY-HORN AND ASSOCIATES, INC.
4001 WILLOW D. ROAD, SUITE 600
WARREN, ILL. 60555
PHONE: (847) 455-4555
WWW.KIMLEY-HORN.COM

USER NAME =	DESIGNED -	REVISED -
DRAWN -	REVISED -	
PLOT SCALE =	CHECKED -	REVISED -
PLOT DATE =	DATE -	REVISED -

STATE OF ILLINOIS
DEPARTMENT OF TRANSPORTATION

TRAFFIC SIGNAL MODERNIZATION PLAN
IL 64 (NORTH AVE) AND FAIR OAKS RD/ANCIENT OAKS DR

SCALE: 1" = 20' SHEET OF SHEETS STA. TO STA.

F.A.P. RTE.	SECTION	COUNTY	TOTAL SHEETS	SHEET NO.
307	2020-263-SUR, SW&TS	DUPAGE	529	149
CONTRACT NO. 62N33				
ILLINOIS FED. AID PROJECT				

EX INTERCONNECT TO
PRINCE CROSSING RD
(TO BE ABANDONED)

EX TRACER CABLE
(TO BE ABANDONED)

 PROTECTED PHASE
 PROTECTED/PERMITTED PHASE
 PEDESTRIAN PHASE
 OVERLAP

TYPE	QUANTITY	UNIT WATTAGE	TOTAL WATTAGE
SIGNAL HEAD 1 OR 3-SECTION	18	11	198
4-SECTION	-	14	-
5-SECTION	4	13	52
PROGRAMMABLE 3-SECTION	-	22	-
4-SECTION	-	32	-
5-SECTION	-	28	-
PEDESTRIAN SIGNAL	-	15	-
CONTROLLER	1	150	150
MASTER CONTROLLER	-	100	-
UPS	1	25	25
DETECTION VIDEO	4	20	80
BLANK-OUT SIGN	-	25	-
NETWORK SWITCH LAYER II OR III	1	35	35
CELLULAR MODEM	-	15	-
PTZ	1	75	75
TOTAL UPS SIZING			615
UPS CHARGING	1	225	225
BATTERY HEATER MAT	1	180	180
CABINET HEATER	1	200	200
FLASHER	-	15	-
LED STREET NAME SIGN	-	120	-
LUMINAIRE	-	240	-



ENERGY SUPPLY:	COMPANY: <u>COMED</u>
	PHONE: <u>(866) 639-3532</u>
	ACCOUNT NUMBER: <u>28380-06047</u>

**STATE OF ILLINOIS
DEPARTMENT OF TRANSPORTATION**

SCALE: N.T.S.	SHEET	OF	SHEETS	STA.	TO STA.
---------------	-------	----	--------	------	---------

TS 12376
IDOT TACTICS
FORMER EAGLE 5A

  ALL DIMENSIONS ARE IN INCHES UNLESS OTHERWISE NOTED



ITEM DESCRIPTION	UNIT	QUANTITY
SIGN PANEL - TYPE 2	SQ FT	105
UNDERGROUND CONDUIT, GALVANIZED STEEL, 2" DIA.	FOOT	5
UNDERGROUND CONDUIT, GALVANIZED STEEL, 3" DIA.	FOOT	90
MAINTENANCE OF EXISTING TRAFFIC SIGNAL INSTALLATION	EACH	1
ELECTRIC CABLE IN CONDUIT, SIGNAL NO. 14 3C	FOOT	551
ELECTRIC CABLE IN CONDUIT, SIGNAL NO. 14 5C	FOOT	3596
ELECTRIC CABLE IN CONDUIT, SIGNAL NO. 14 7C	FOOT	1026
ELECTRIC CABLE IN CONDUIT, SERVICE, NO. 6 2 C	FOOT	549
ELECTRIC CABLE IN CONDUIT, EQUIPMENT GROUNDING CONDUCTOR, NO. 6 1C	FOOT	114
TRAFFIC SIGNAL POST, GALVANIZED STEEL 16 FT.	EACH	2
STEEL MAST ARM ASSEMBLY AND POLE, 24 FT.	EACH	1
STEEL MAST ARM ASSEMBLY AND POLE, 64 FT.	EACH	1
STEEL MAST ARM ASSEMBLY AND POLE, 66 FT.	EACH	1
STEEL MAST ARM ASSEMBLY AND POLE WITH DUAL MAST ARMS, 32 FT. AND 40 FT.	EACH	1
CONCRETE FOUNDATION, TYPE A	FOOT	8
CONCRETE FOUNDATION, TYPE E 30-INCH DIAMETER	FOOT	10
CONCRETE FOUNDATION, TYPE E 36-INCH DIAMETER	FOOT	14
CONCRETE FOUNDATION, TYPE E 42-INCH DIAMETER	FOOT	50
DRILL EXISTING HANDHOLE	EACH	5
SIGNAL HEAD, LED, 1-FACE, 3-SECTION, MAST-ARM MOUNTED	EACH	14
SIGNAL HEAD, LED, 1-FACE, 3-SECTION, BRACKET MOUNTED	EACH	4
SIGNAL HEAD, LED, 1-FACE, 5-SECTION, BRACKET MOUNTED	EACH	1
SIGNAL HEAD, LED, 1-FACE, 5-SECTION, MAST-ARM MOUNTED	EACH	3
TRAFFIC SIGNAL BACKPLATE, LOUVERED, FORMED PLASTIC	EACH	17
RELOCATE EXISTING EMERGENCY VEHICLE PRIORITY SYSTEM, DETECTOR UNIT	EACH	2
REMOVE ELECTRIC CABLE FROM CONDUIT	FOOT	2
REMOVE EXISTING TRAFFIC SIGNAL EQUIPMENT	EACH	1
REMOVE EXISTING CONCRETE FOUNDATION	EACH	5
CLOSED CIRCUIT TELEVISION DOME CAMERA, HD	EACH	1
EMERGENCY VEHICLE PRIORITY SYSTEM LINE SENSOR CABLE, NO. 20 3/C	FOOT	549
OUTDOOR RATED NETWORK CABLE	FOOT	258
SERVICE INSTALLATION, GROUND MOUNTED, METERED	EACH	1
REMOTE CONTROLLED VIDEO SYSTEM	EACH	1
LAYER II (DATALINK) SWITCH	EACH	1
TERMINATE FIBER IN CABINET	EACH	12
TACTICS LICENSE EXPANSION	EACH	1
FULL-ACTUATED CONTROLLER IN EXISTING CABINET	EACH	1
REMOVE AND REPLACE BATTERIES FOR UNINTERRUPTABLE POWER SUPPLY, EXTENDED	EACH	1
FIBER OPTIC INTERCONNECT CENTER, 48 PORT	EACH	1
LED SIGNAL FACE, LENS COVER	EACH	22
VIDEO VEHICLE DETECTION SYSTEM, SINGLE APPROACH	EACH	4
CAMERA MOUNTING ASSEMBLY	EACH	1

**TS 12376
IDOT TACTICS
FORMER EAGLE 5A**

NOTES

- THE EXISTING TRAFFIC SIGNAL EQUIPMENT SHALL NOT BE REMOVED UNTIL THE PROPOSED TRAFFIC SIGNAL EQUIPMENT IS FULLY OPERATIONAL OR AS DIRECTED BY THE ENGINEER.
- ALL EXISTING TRAFFIC SIGNAL CABLE NO LONGER REQUIRED SHALL BE REMOVED.



MATCH LINE STA 1311+50

MATCH LINE STA 1316+50

RELOCATION NOTES

THE FOLLOWING EXISTING TRAFFIC SIGNAL EQUIPMENT SHALL BE REMOVED BY THE CONTRACTOR, SAFELY STORED AND RELOCATED TO THE PROPOSED MAST ARMS, POSTS, AND TRAFFIC SIGNAL CONTROLLER CABINET.

- | | | |
|---|------|---------------------|
| 2 | EACH | CONFIRMATION BEACON |
| 2 | EACH | LIGHT DETECTOR |
| 1 | EACH | ELECTRIC METER |

REMOVAL NOTES

THE FOLLOWING ITEMS SHALL BE REMOVED BY THE CONTRACTOR AND SHALL BE DISPOSED OF BY THEM OUTSIDE THE RIGHT-OF-WAY AT THEIR EXPENSE. THE SALVAGE VALUE OF THE REMOVED EQUIPMENT SHALL BE REFLECTED IN CONTRACT BID PRICE.

- | | | |
|----|------|----------------------------|
| 4 | EACH | STREET NAME SIGN PANEL |
| 20 | EACH | 3-SECTION SIGNAL HEAD |
| 4 | EACH | 5-SECTION SIGNAL HEAD |
| 2 | EACH | MAST ARM ASSEMBLY AND POLE |
| 14 | EACH | TRAFFIC SIGNAL BACKPLATE |
| 2 | EACH | TRAFFIC SIGNAL POST |

MATCH LINE A

MATCH LINE B

STATE OF ILLINOIS
DEPARTMENT OF TRANSPORTATION

TRAFFIC SIGNAL EQUIPMENT REMOVAL PLAN
IL 64 (NORTH AVE) AND COUNTY FARM RD

SCALE: 1" = 20' SHEET OF SHEETS STA. TO STA.

TS 6425
IDOT TACTICS
FORMER EAGLE 2E

Kimley»Horn

© 2023 KIMLEY-HORN AND ASSOCIATES, INC.
4001 WILMINGTON ROAD, SUITE 600
WARREN, ILL. 60555
PHONE: 815.447.4555
WWW.KHAFIRM.COM

USER NAME =	DESIGNED -	REVISED -
	DRAWN -	REVISED -
PLOT SCALE =	CHECKED -	REVISED -
PLOT DATE =	DATE -	REVISED -

F.A.P. RTE.	SECTION	COUNTY	TOTAL SHEETS	SHEET NO.
307	2020-263-SUR, SW&TS	DUPAGE	529	152
				CONTRACT NO. 62N33
		ILLINOIS	FED. AID PROJECT	

MODEL: Default
FILE: \\naulpc-prod\h-pw-bentley.com\h-pw-d1\Documents\01 Active Projects\IMW\CHS-168950\00 - IL 64\Phase II\2 Design\CAD\Plan_Sheets\Signal\West Corridor_Signals\01081714-IL-64-52_KIM.dgn







USER NAME =	DESIGNED -	REVISED -
	DRAWN -	REVISED -
PLOT SCALE =	CHECKED -	REVISED -
PLOT DATE =	DATE -	REVISED -

STATE OF ILLINOIS
DEPARTMENT OF TRANSPORTATION

TRAFFIC SIGNAL EQUIPMENT REMOVAL PLAN
IL 64 (NORTH AVE) AND COUNTY FARM RD


SCALE: 1" = 20' SHEET OF SHEETS STA. TO STA.

F.A.P. RTE.	SECTION	COUNTY	TOTAL SHEETS	SHEET NO.
307	2020-263-SUR,SW&TS	DUPAGE	529	153
CONTRACT NO. 62N33				
ILLINOIS FED. AID PROJECT				

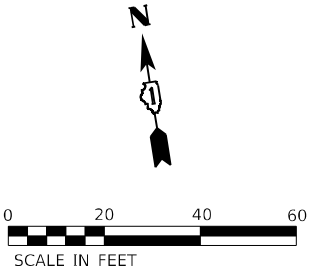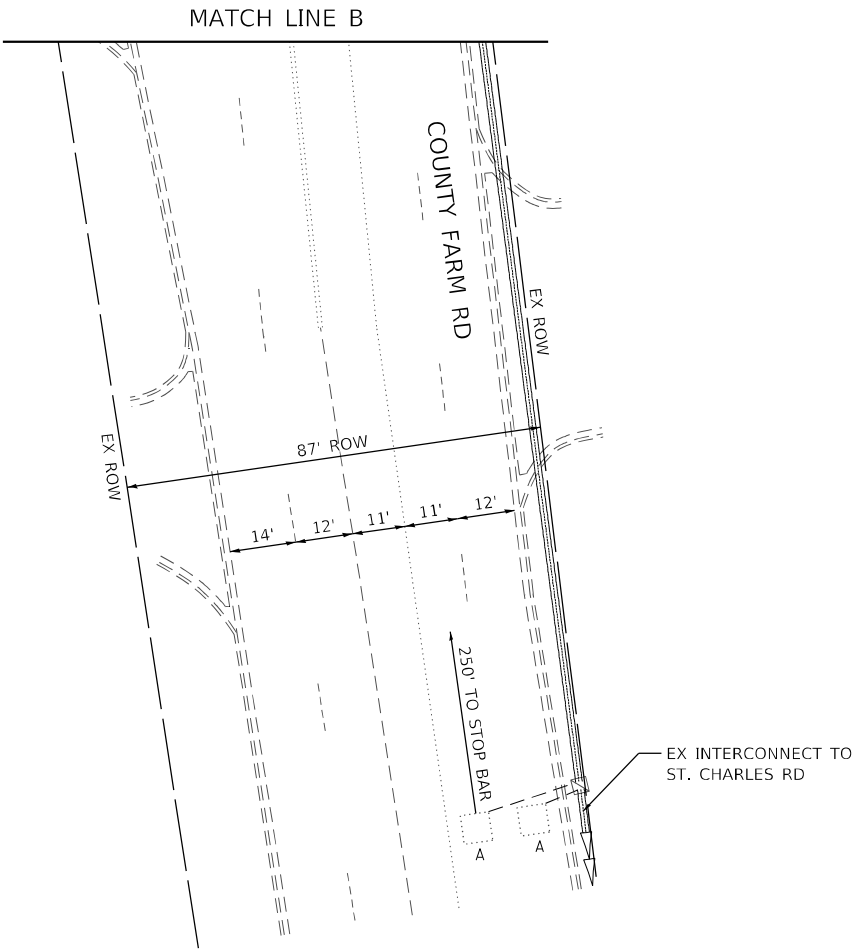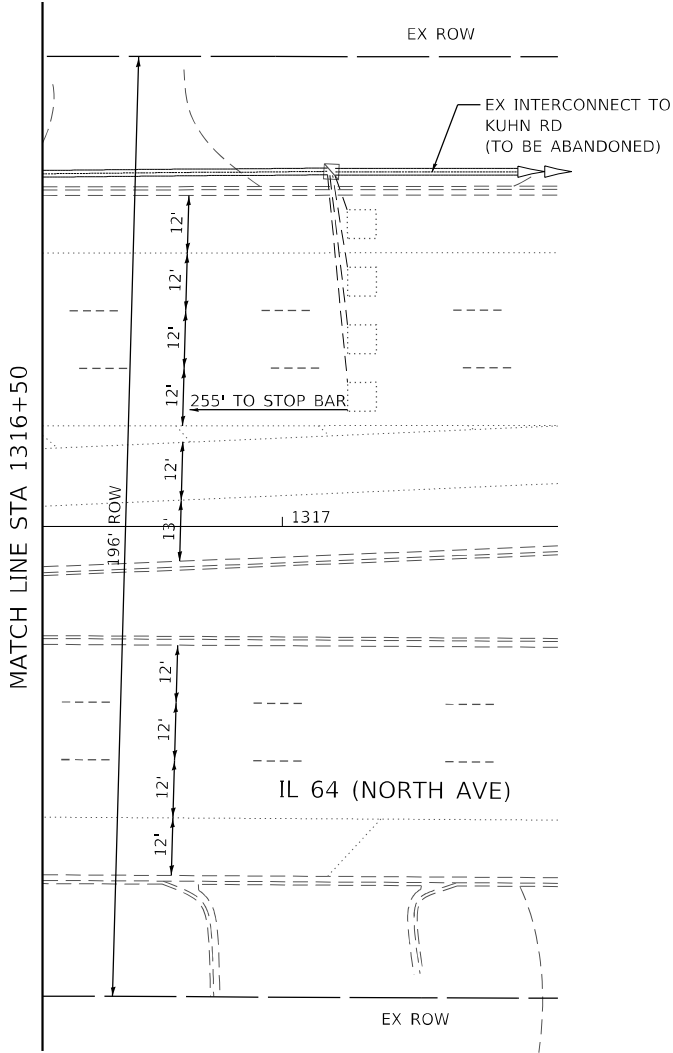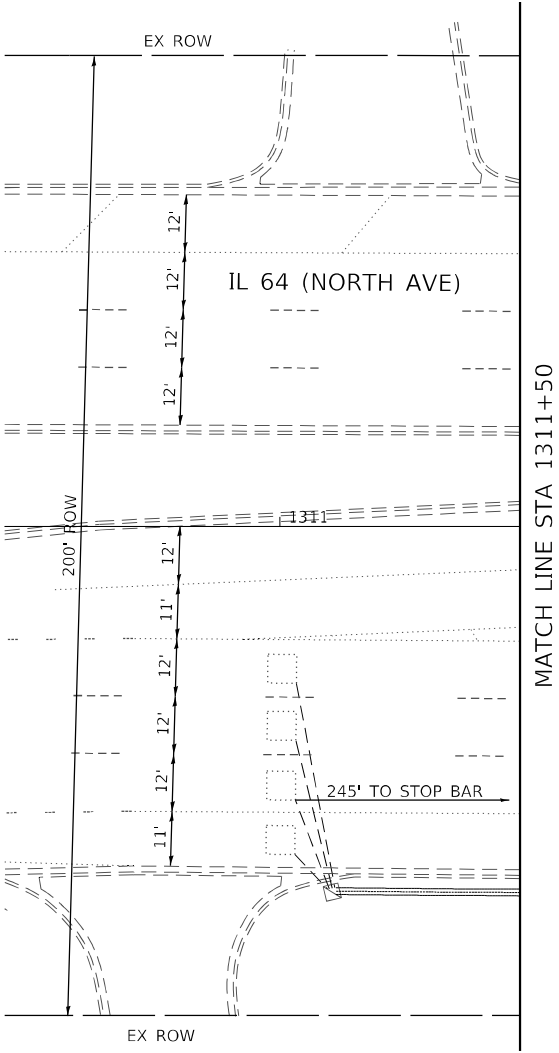

TS 6425
IDOT TACTICS
FORMER EAGLE 2E

1. ALL PROPOSED TRAFFIC SIGNAL CABLE SHALL BE ROUTED THROUGH THE PROPOSED CONDUIT.
2. A SEPARATE LEAD-IN CABLE SHALL BE INSTALLED FOR THE DETECTOR LOOPS ON IL 64 (NORTH AVE).
3. THE EXISTING SERVICE METER SHALL BE RELOCATED TO THE PROPOSED GROUND MOUNTED SERVICE CABINET. THE EXISTING SERVICE METER HOUSING SHALL REMAIN AT THE EXISTING TRAFFIC SIGNAL CONTROLLER CABINET AND ALL HOLES BETWEEN THE EXISTING HOUSING AND THE EXISTING CABINET SHALL BE PLUGGED. THIS WORK SHALL BE INCLUDED IN THE PAY ITEM SERVICE INSTALLATION, GROUND MOUNTED, METERED.
4. PROPOSED CONDUIT SHALL BE SPLICED TO THE EXISTING CONDUIT AND EXTENDED VERTICALLY THROUGH THE PROPOSED FOUNDATION AT THE GROUND MOUNTED SERVICE LOCATION. THE COST OF THE CONDUIT SHALL BE INCLUDED IN THE COST OF CONCRETE FOUNDATION, TYPE A.
5. CONTRACTOR TO INSTALL A NEW LAYER II SWITCH IN EXISTING TRAFFIC SIGNAL CABINET LOCATED AT COUNTY FARM RD AND ST. CHARLES RD. TO ESTABLISH A NETWORK CONNECTION TO THE PROPOSED FIBER OPTIC COMMUNICATIONS BACKBONE (DCF-NO-002) TO BE INSTALLED AS PART OF THIS PROJECT.

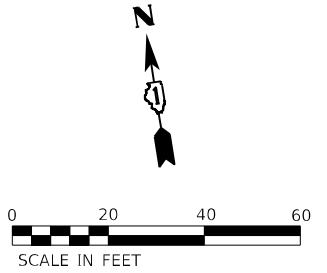

R10-5
30" X 36"
(8 REQUIRED)

TS 6425
IDOT TACTICS
FORMER EAGLE 2E

MODEL: Default
FILE NAME: p:\sub-pw\bartley.com\k-h-pw-d1\Documents\01 Active Projects\MW\CHS-168950\00 - IL 64\Phase 01\2 Design\CAD\Plan Streets\Signal\West Corridor_Signal\01081714-IL-64-K4A.dgn

Kimley»Horn

© 2021 KIMLEY-HORN AND ASSOCIATES, INC.
4001 WHITE OAK ROAD, SUITE 600
WARREN, ILL. 60555
PHONE: 815.447.4555
WWW.KIMLEY-HORN.COM

USER NAME	=	DESIGNED	-
		DRAWN	-
PLOT SCALE	=	CHECKED	-
PLOT DATE	=	DATE	-
		REVISED	-
		REVISED	-
		REVISED	-
		REVISED	-



STATE OF ILLINOIS
DEPARTMENT OF TRANSPORTATION

TRAFFIC SIGNAL MODERNIZATION PLAN
IL 64 (NORTH AVE) AND COUNTY FARM RD


SCALE: 1" = 20' SHEET OF SHEETS STA. TO STA.

F.A.P. RTE.	SECTION	COUNTY	TOTAL SHEETS	SHEET NO.
307	2020-263-SUR,SW&TS	DUPAGE	529	155
CONTRACT NO. 62N33				
		ILLINOIS	FED. AID PROJECT	

TS 6425
IDOT TACTICS
FORMER EAGLE 2E

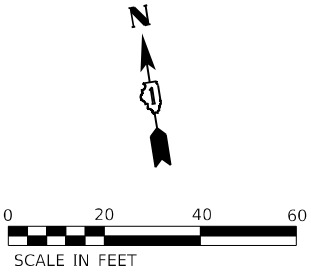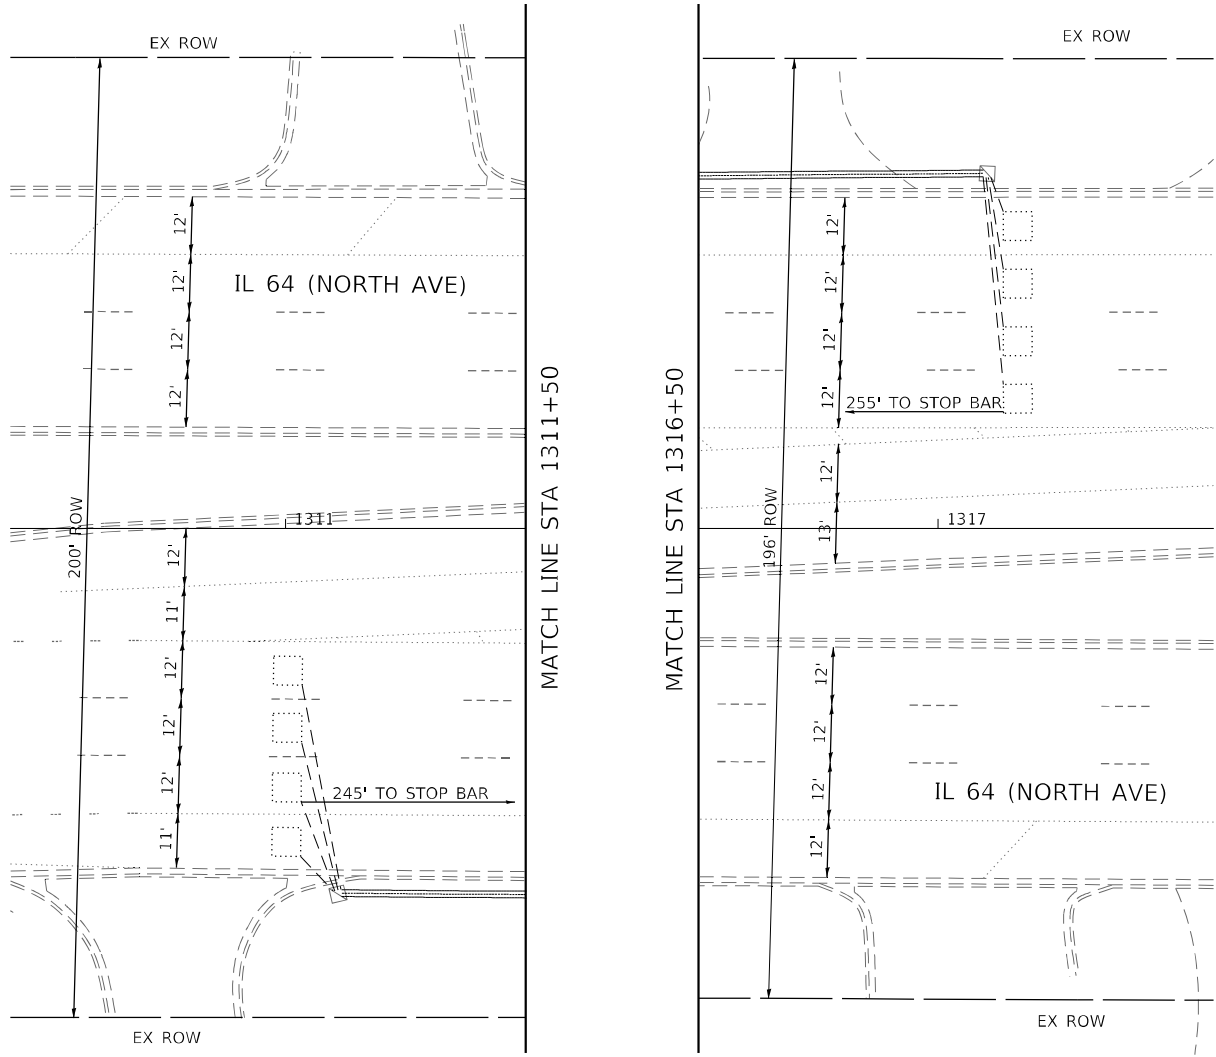

EXISTING AND PROPOSED
CONTROLLER SEQUENCE

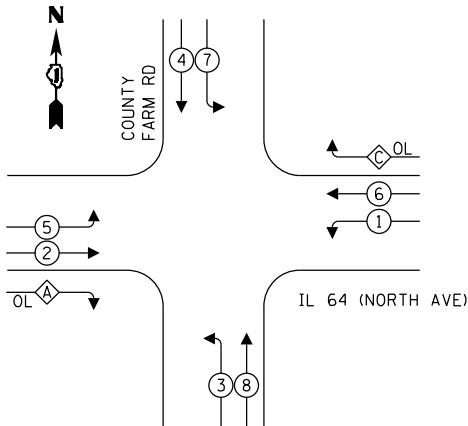


LEGEND:

- ← (⊛) — PROTECTED PHASE
- ← - (⊛) - — PROTECTED/PERMITTED PHASE
- ← (⊛) → — PEDESTRIAN PHASE
- ← (⊛) OL — OVERLAP

OVERLAP LETTER		PERMISSIVE PHASE		PROTECTED PHASE
A	=	2	+	3
C	=	6	+	7

EXISTING AND PROPOSED EMERGENCY
VEHICLE PREEMPTION SEQUENCE

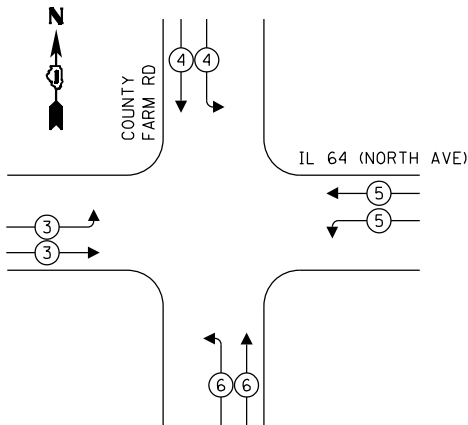


TRAFFIC SIGNAL
ELECTRICAL SERVICE REQUIREMENTS

TYPE	QUANTITY	UNIT WATTAGE	TOTAL WATTAGE
SIGNAL HEAD 1 OR 3-SECTION	20	11	220
4-SECTION	-	14	-
5-SECTION	4	13	52
PROGRAMMABLE 3-SECTION	-	22	-
4-SECTION	-	32	-
5-SECTION	-	28	-
PEDESTRIAN SIGNAL	-	15	-
CONTROLLER	1	150	150
MASTER CONTROLLER	-	100	-
UPS	1	25	25
DETECTION VIDEO	2	20	40
BLANK-OUT SIGN	-	25	-
NETWORK SWITCH LAYER II OR III	1	35	35
CELLULAR MODEM	-	15	-
PTZ	1	75	75
TOTAL UPS SIZING		597	
UPS CHARGING	1	225	225
BATTERY HEATER MAT	1	180	180
CABINET HEATER	1	200	200
FLASHER	-	15	-
LED STREET NAME SIGN	-	120	-
LUMINAIRE	-	240	-
TOTAL SERVICE WIRE SIZING		1202	

ENERGY COSTS TO:
ILLINOIS DEPARTMENT OF TRANSPORTATION
201 W CENTER CT
SCHAUMBURG, IL 60196

ENERGY SUPPLY: COMPANY: COMED
PHONE: (866) 639-3532
ACCOUNT NUMBER: 28380-06047

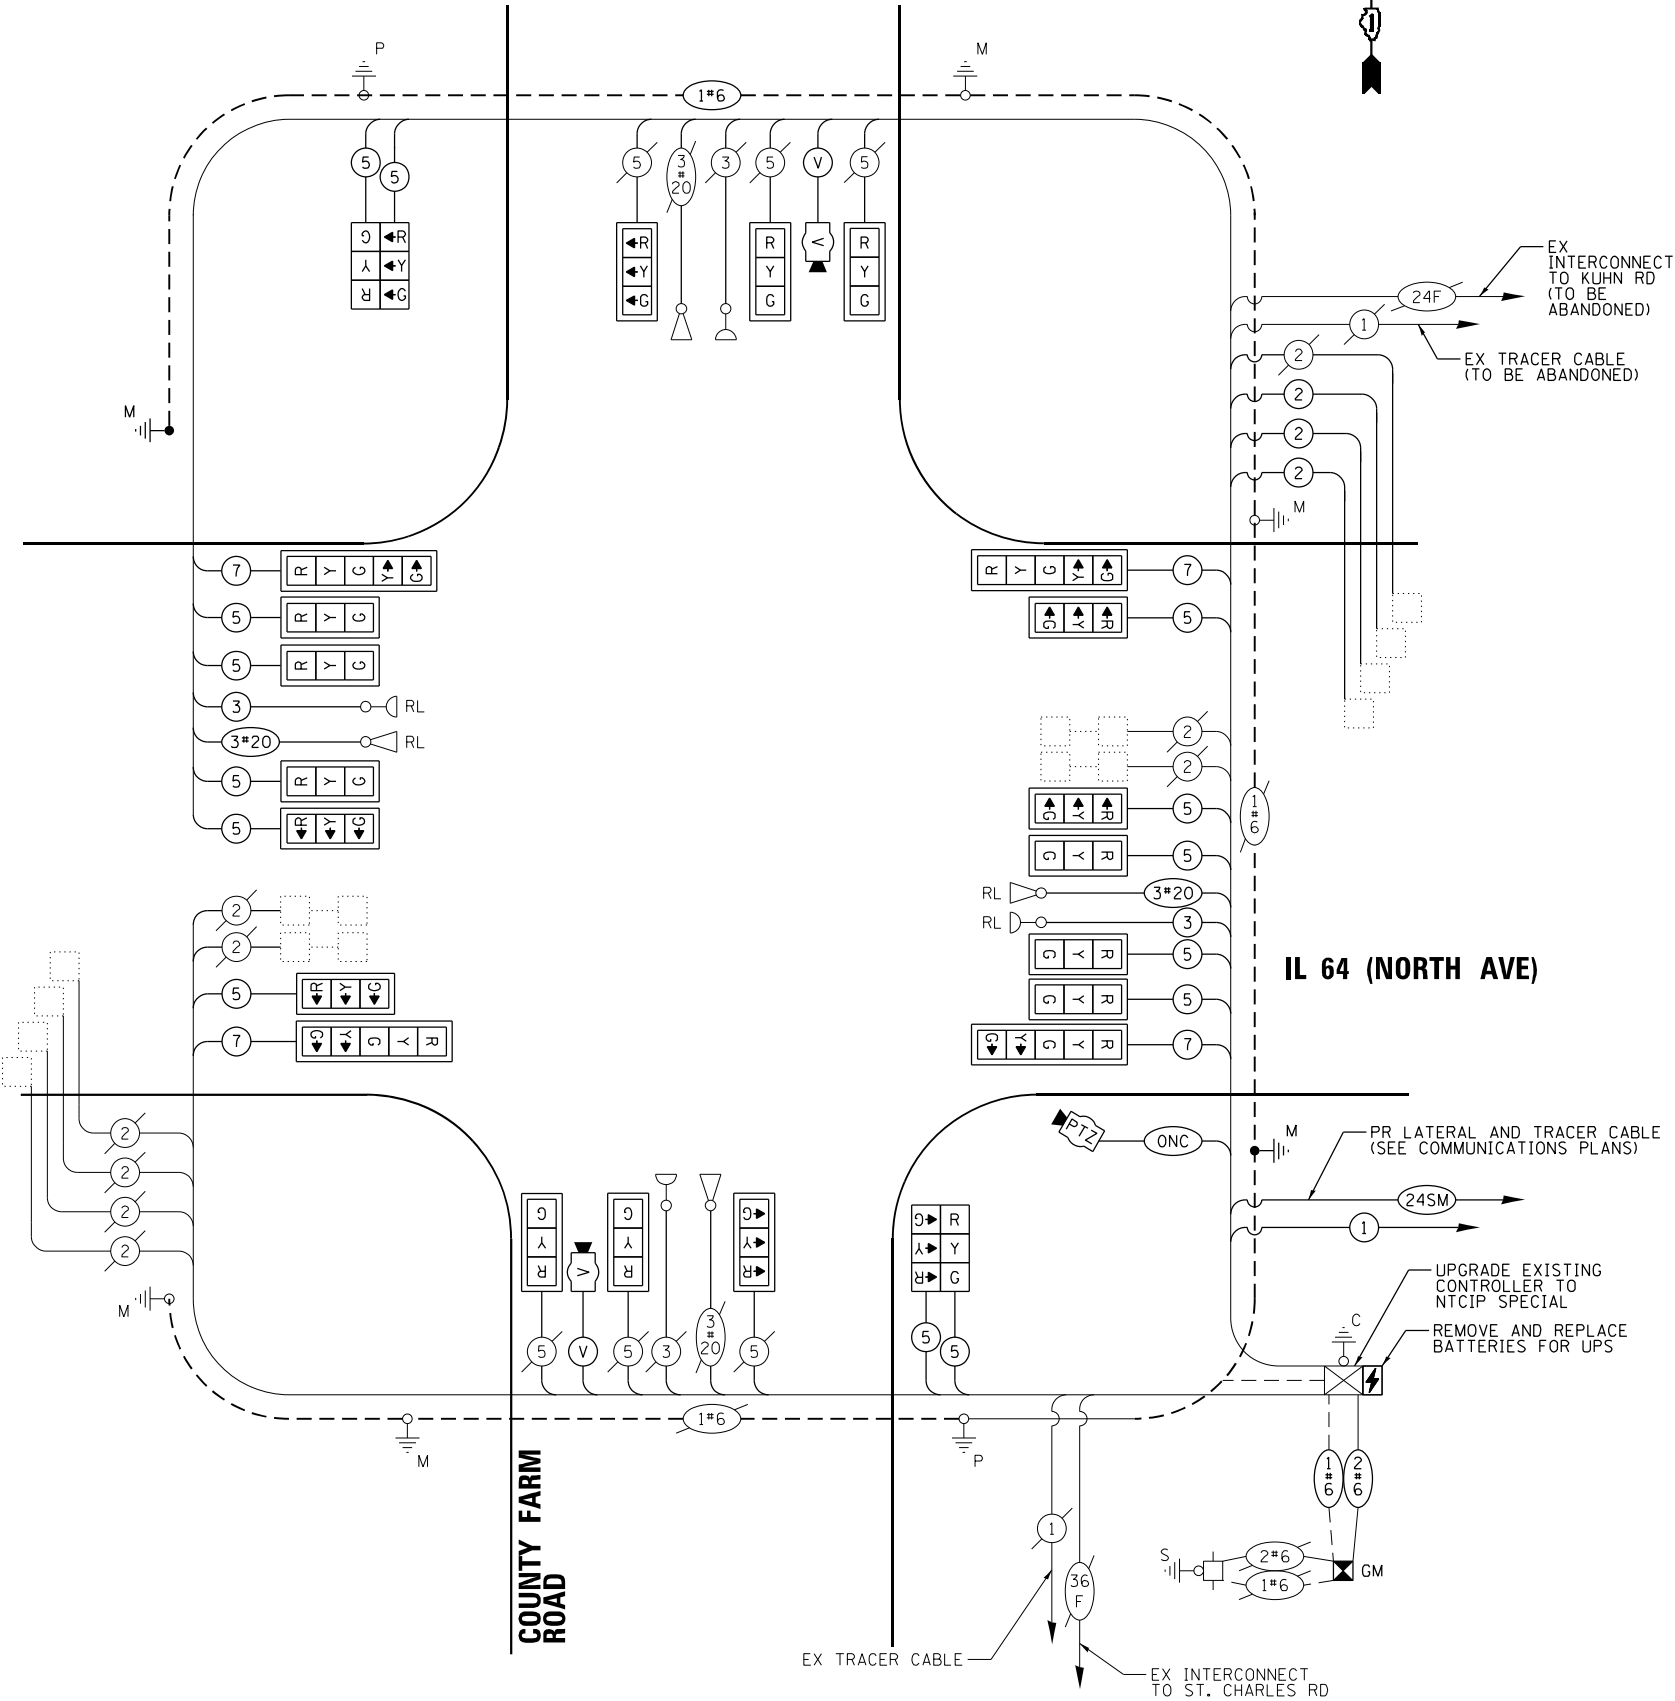

CABLE PLAN
(NOT TO SCALE)

TS 6425
IDOT TACTICS
FORMER EAGLE 2E

KimleyHorn

© 2023 KIMLEY-HORN AND ASSOCIATES, INC.
4001 WILMINGTON ROAD, SUITE 600
WARREN, IL 60555
PHONE: (847) 455-4555
WWW.KIMLEY-HORN.COM

USER NAME	=	
PLOT SCALE	=	
PLOT DATE	=	

DESIGNED	-	REVISED	-
DRAWN	-	REVISED	-
CHECKED	-	REVISED	-
DATE	-	REVISED	-

STATE OF ILLINOIS
DEPARTMENT OF TRANSPORTATION


CABLE PLAN, PHASE DESIGNATION DIAGRAM, AND
EMERGENCY VEHICLE PREEMPTION SEQUENCE
IL 64 (NORTH AVE) AND COUNTY FARM RD

SCALE: N.T.S. SHEET OF SHEETS STA. TO STA.

F.A.P. RTE.	SECTION	COUNTY	TOTAL SHEETS	SHEET NO.
307	2020-263-SUR, SW&TS	DUPAGE	529	156
				CONTRACT NO. 62N33
		ILLINOIS	FED. AID PROJECT	

SIGN PANEL – TYPE 2

ALL DIMENSIONS ARE IN INCHES UNLESS OTHERWISE NOTED

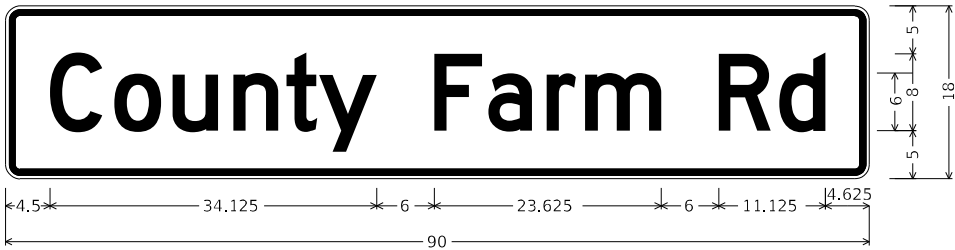

DESIGN SERIES	AREA (SQ. FT)	SIGN PANEL TYPE	SHEETING TYPE	QTY. REQUIRED
D	11.25	2	ZZ	2



DESIGN SERIES	AREA (SQ. FT)	SIGN PANEL TYPE	SHEETING TYPE	QTY. REQUIRED
D	12.5	2	ZZ	2

SCHEDULE OF QUANTITIES

ITEM DESCRIPTION	UNIT	QUANTITY
SIGN PANEL - TYPE 2	SQ. FT.	47.5
UNDERGROUND CONDUIT, GALVANIZED STEEL, 2" DIA.	FOOT	5
UNDERGROUND CONDUIT, GALVANIZED STEEL, 3" DIA.	FOOT	48
UNDERGROUND CONDUIT, GALVANIZED STEEL, 4" DIA.	FOOT	462
MAINTENANCE OF EXISTING TRAFFIC SIGNAL INSTALLATION	EACH	1
ELECTRIC CABLE IN CONDUIT, SIGNAL NO. 14 3C	FOOT	652
ELECTRIC CABLE IN CONDUIT, SIGNAL NO. 14 5C	FOOT	4168
ELECTRIC CABLE IN CONDUIT, SIGNAL NO. 14 7C	FOOT	1258
ELECTRIC CABLE IN CONDUIT, LEAD-IN, NO. 14 1 PAIR	FOOT	1422
ELECTRIC CABLE IN CONDUIT, SERVICE, NO. 6 2 C	FOOT	36
ELECTRIC CABLE IN CONDUIT, EQUIPMENT GROUNDING CONDUCTOR, NO. 6 1C	FOOT	546
TRAFFIC SIGNAL POST, GALVANIZED STEEL 16 FT.	EACH	2
STEEL MAST ARM ASSEMBLY AND POLE, 75 FT.	EACH	2
CONCRETE FOUNDATION, TYPE A	FOOT	4
CONCRETE FOUNDATION, TYPE E 42-INCH DIAMETER	FOOT	50
DRILL EXISTING HANDHOLE	EACH	10
SIGNAL HEAD, LED, 1-FACE, 3-SECTION, MAST-ARM MOUNTED	EACH	16
SIGNAL HEAD, LED, 1-FACE, 3-SECTION, BRACKET MOUNTED	EACH	4
SIGNAL HEAD, LED, 1-FACE, 5-SECTION, MAST-ARM MOUNTED	EACH	4
TRAFFIC SIGNAL BACKPLATE, LOUVERED, FORMED PLASTIC	EACH	20
* RELOCATE EXISTING EMERGENCY VEHICLE PRIORITY SYSTEM, DETECTOR UNIT	EACH	2
REMOVE ELECTRIC CABLE FROM CONDUIT	FOOT	8082
REMOVE EXISTING TRAFFIC SIGNAL EQUIPMENT	EACH	1
REMOVE EXISTING HANDHOLE	EACH	1
REMOVE EXISTING CONCRETE FOUNDATION	EACH	2
CLOSED CIRCUIT TELEVISION DOME CAMERA, HD	EACH	1
* EMERGENCY VEHICLE PRIORITY SYSTEM LINE SENSOR CABLE, NO. 20 3/C	FOOT	652
OUTDOOR RATED NETWORK CABLE	FOOT	138
SERVICE INSTALLATION, GROUND MOUNTED, METERED	EACH	1
REMOTE CONTROLLED VIDEO SYSTEM	EACH	1
LAYER II (DATALINK) SWITCH	EACH	2
TERMINATE FIBER IN CABINET	EACH	24
UPGRADE EXISTING CONTROLLER TO NTCIP SPECIAL	EACH	1
TACTICS LICENSE EXPANSION	EACH	1
REMOVE AND REPLACE BATTERIES FOR UNINTERRUPTABLE POWER SUPPLY, EXTENDED	EACH	1
FIBER OPTIC INTERCONNECT CENTER, 48 PORT	EACH	1
LED SIGNAL FACE, LENS COVER	EACH	24
VIDEO VEHICLE DETECTION SYSTEM, SINGLE APPROACH	EACH	2


* - 100% COST TO THE VILLAGE OF CAROL STREAM

TS 6425
IDOT TACTICS
FORMER EAGLE 2E

MODEL: Default
FILE: Kimley-Horn\ut-pw-bentley.com\khp-w-d\Documents\01 Active Projects\IMW-CHS-68095\100 - IL 64\Phase 1\12 Design\CAD\Plan_Sheets\Sign\12-IL-Rte-56_KHA.dgn

KimleyHorn © 2023 KIMLEY-HORN AND ASSOCIATES, INC. 4001 HWY 10, ROAD SUITE 600 WARREN, IL 60555 PHONE: 815.447.4555 WWW.KIMLEY-HORN.COM	USER NAME =	DESIGNED - JJT	REVISED -	STATE OF ILLINOIS DEPARTMENT OF TRANSPORTATION	MAST ARM MOUNTED STREET NAME SIGNS AND SCHEDULE OF QUANTITIES IL 64 (NORTH AVE) AND COUNTY FARM RD	SCALE: N.T.S.	SHEET OF SHEETS	STA. TO STA.	F.A.P. RTE.	SECTION	COUNTY	TOTAL SHEETS	SHEET NO.
		DRAWN - JRR	REVISED -						307	2020-263-SUR,SW&TS	DUPAGE	529	157
	PLOT SCALE =	CHECKED - SRS	REVISED -						CONTRACT NO. 62N33				
	PLOT DATE =	DATE - 3/21/2025	REVISED -						ILLINOIS FED. AID PROJECT				

1. THE EXISTING TRAFFIC SIGNAL EQUIPMENT SHALL NOT BE REMOVED UNTIL THE PROPOSED TRAFFIC SIGNAL EQUIPMENT IS FULLY OPERATIONAL OR AS DIRECTED BY THE ENGINEER.
2. ALL EXISTING TRAFFIC SIGNAL CABLE NO LONGER REQUIRED SHALL BE REMOVED.

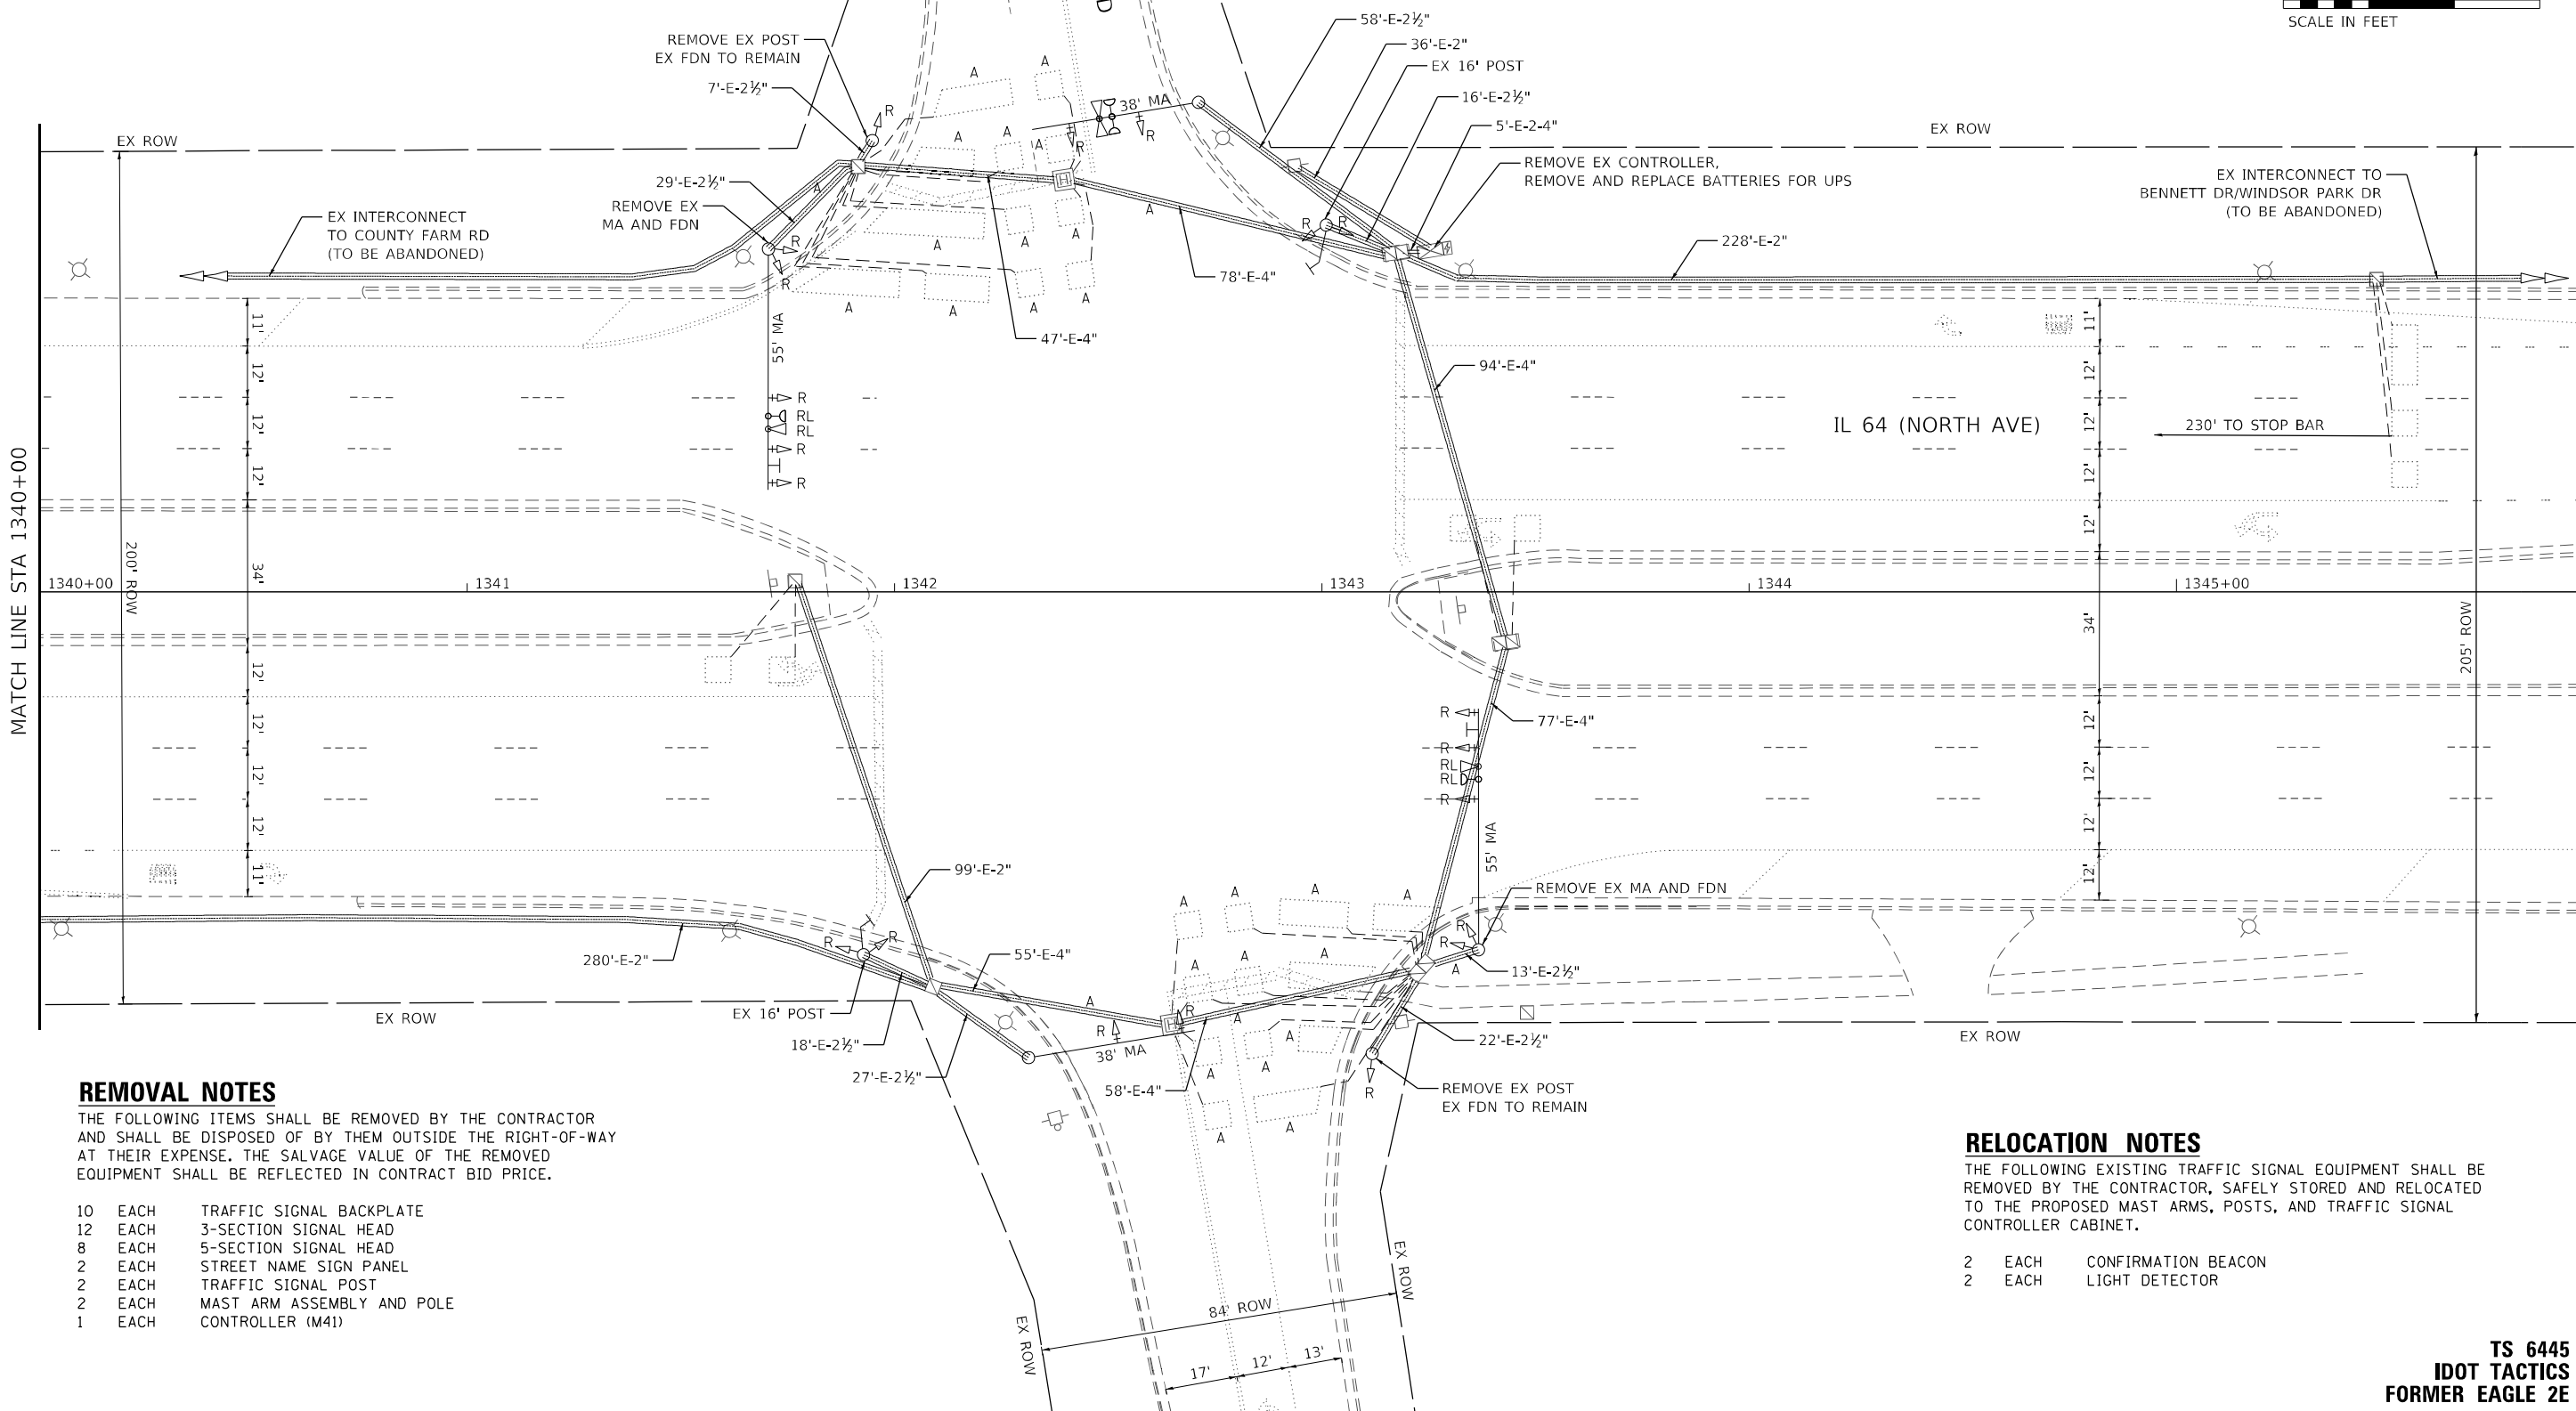



THE FOLLOWING ITEMS SHALL BE REMOVED BY THE CONTRACTOR AND SHALL BE DISPOSED OF BY THEM OUTSIDE THE RIGHT-OF-WAY AT THEIR EXPENSE. THE SALVAGE VALUE OF THE REMOVED EQUIPMENT SHALL BE REFLECTED IN CONTRACT BID PRICE.

10	EACH	TRAFFIC SIGNAL BACKPLATE
12	EACH	3-SECTION SIGNAL HEAD
8	EACH	5-SECTION SIGNAL HEAD
2	EACH	STREET NAME SIGN PANEL
2	EACH	TRAFFIC SIGNAL POST
2	EACH	MAST ARM ASSEMBLY AND POLE
1	EACH	CONTROLLER (M41)

THE FOLLOWING EXISTING TRAFFIC SIGNAL EQUIPMENT SHALL BE REMOVED BY THE CONTRACTOR, SAFELY STORED AND RELOCATED TO THE PROPOSED MAST ARMS, POSTS, AND TRAFFIC SIGNAL CONTROLLER CABINET.

2 EACH CONFIRMATION BEACON
2 EACH LIGHT DETECTOR

TS 6445
IDOT TACTICS
FORMER EAGLE 2E

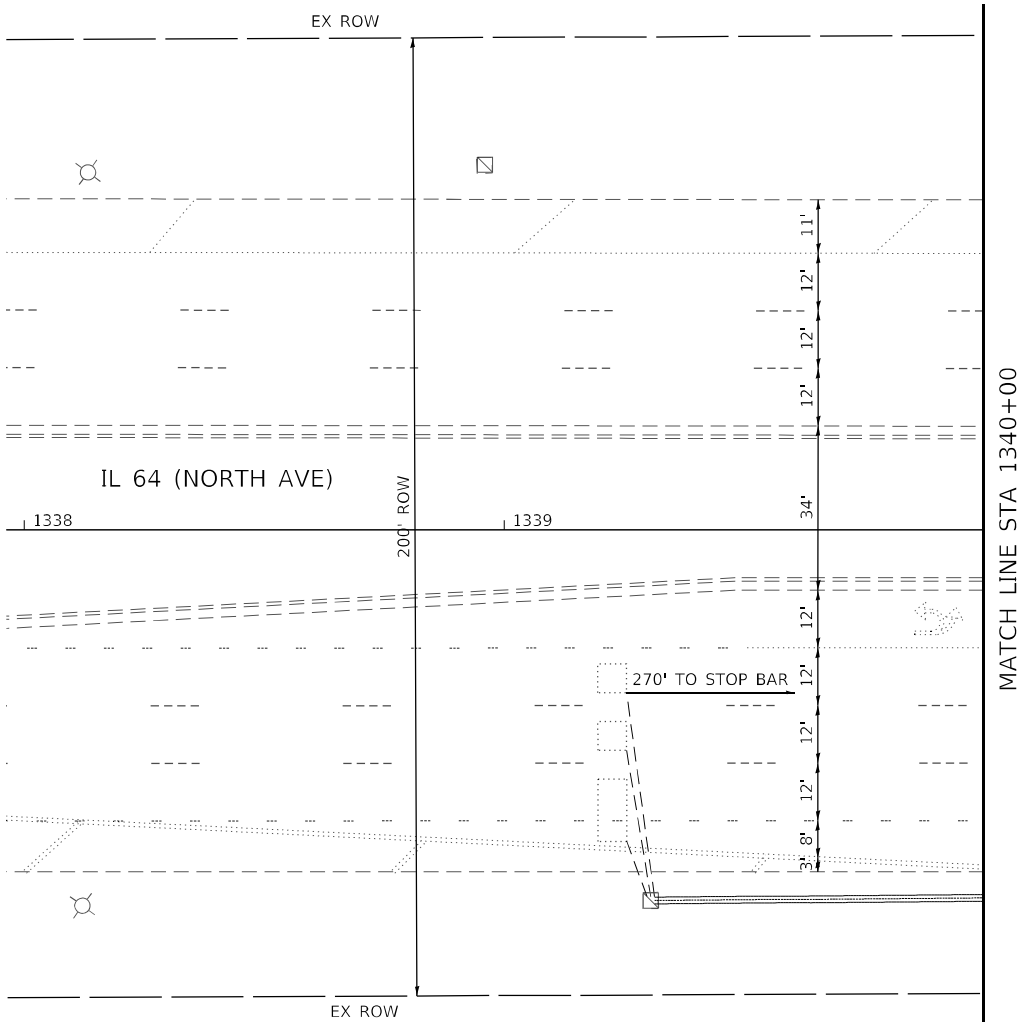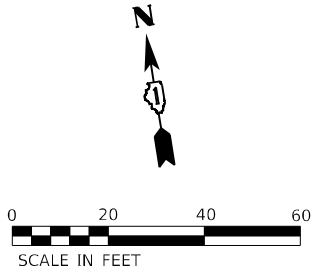

MODEL: Default
FILE NAME: p:\sub-pw\bartley.com\k-h-pw-d1\Documents\01 Active Projects\MW\CL-S-160950\00 - IL 64\Phase 1\12 Design\CAD\Plan Sheets\Signal\West Corridor_Signal\010817-14-14-58_K44.dgn



USER NAME =	DESIGNED -	REVISED -
	DRAWN -	REVISED -
PLOT SCALE =	CHECKED -	REVISED -
PLOT DATE =	DATE -	REVISED -


STATE OF ILLINOIS
DEPARTMENT OF TRANSPORTATION

TRAFFIC SIGNAL EQUIPMENT REMOVAL PLAN IL 64 (NORTH AVE) AND KUHN RD			
SCALE: 1" = 20'	SHEET	OF	SHEETS
STA.		TO STA.	

F.A.P. RTE.	SECTION	COUNTY	TOTAL SHEETS	SHEET NO.
307	2020-263-SUR,SW&TS	DUPAGE	529	159
CONTRACT NO. 62N33				
		ILLINOIS	FED. AID PROJECT	

TS 6445
IDOT TACTICS
FORMER EAGLE 2E

MODEL: Default
FILE: \\kimley-horn-bentley.com\khp\p4\1\Documents\01 Active Projects\IMW-CHS-68059\00 - IL 64Phase II\2 Design\CAD\Plan_Sheets\Signal\West_Corridor_Signals\010817-14-rt-ts-59_KHM.dgn

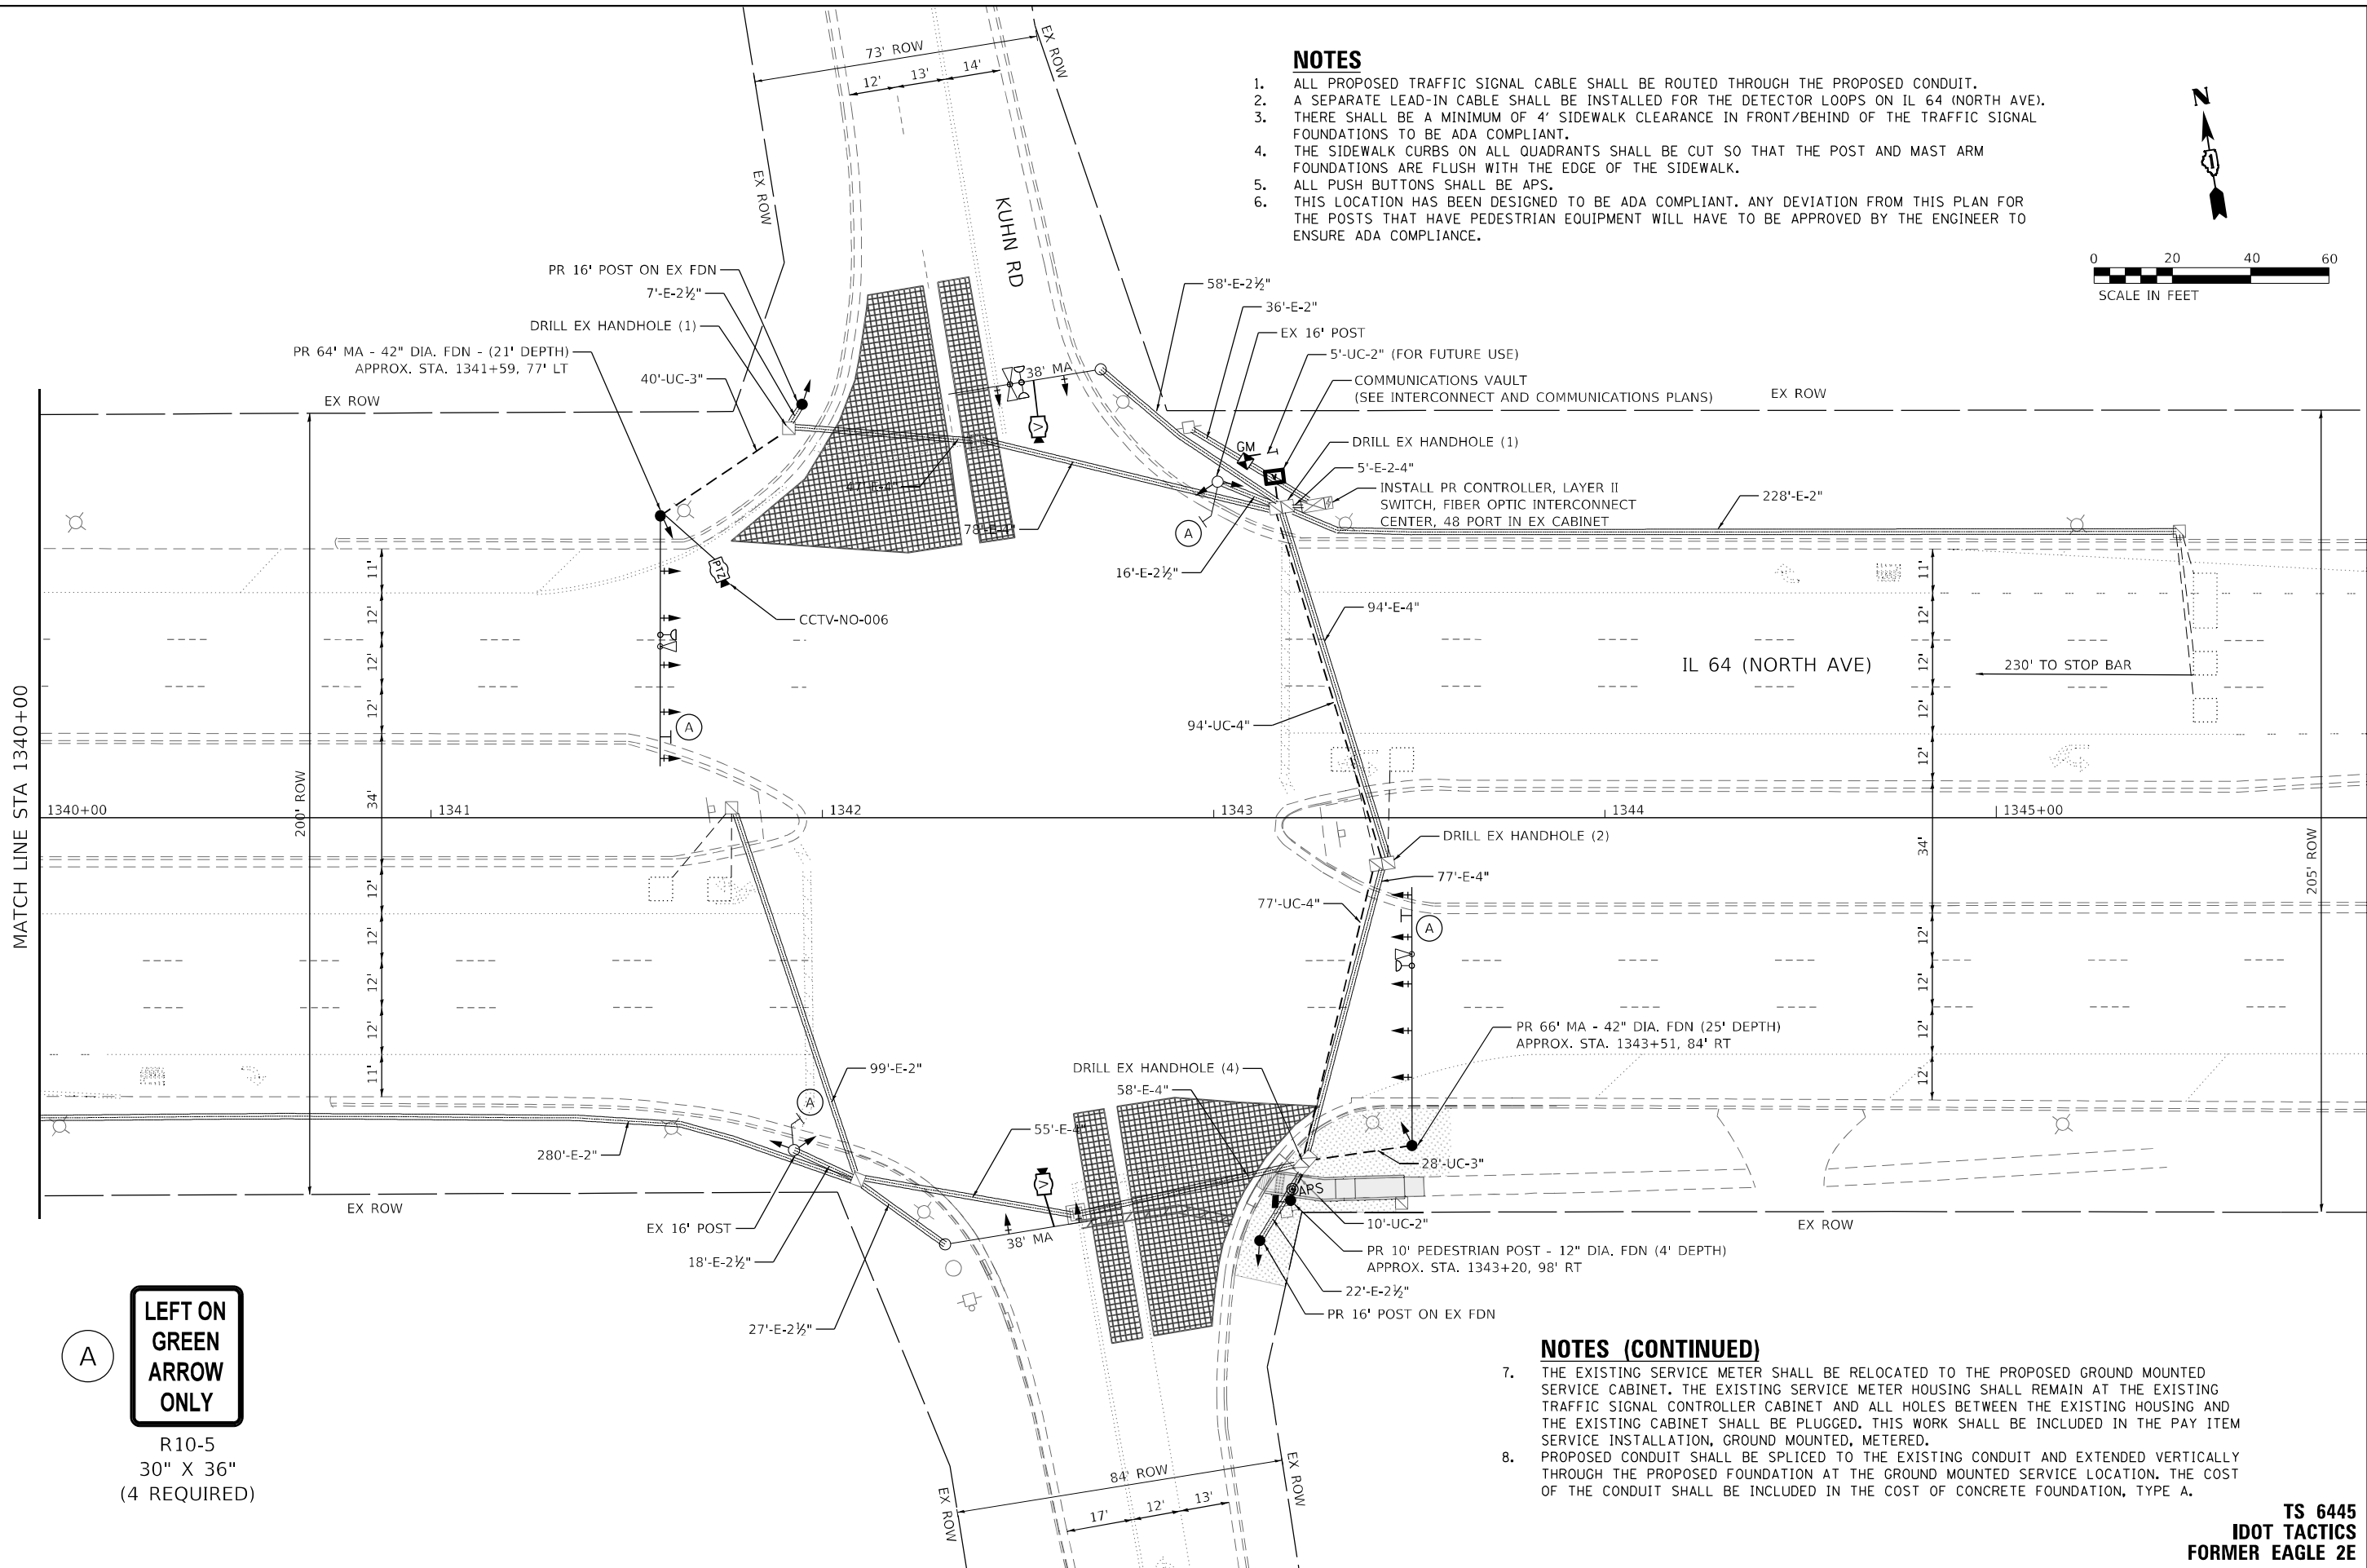

**LEFT ON
GREEN
ARROW
ONLY**

R10-5
30" X 36"
(4 REQUIRED)

NOTES

1. ALL PROPOSED TRAFFIC SIGNAL CABLE SHALL BE ROUTED THROUGH THE PROPOSED CONDUIT.
2. A SEPARATE LEAD-IN CABLE SHALL BE INSTALLED FOR THE DETECTOR LOOPS ON IL 64 (NORTH AVE).
3. THERE SHALL BE A MINIMUM OF 4' SIDEWALK CLEARANCE IN FRONT/BEHIND OF THE TRAFFIC SIGNAL FOUNDATIONS TO BE ADA COMPLIANT.
4. THE SIDEWALK CURBS ON ALL QUADRANTS SHALL BE CUT SO THAT THE POST AND MAST ARM FOUNDATIONS ARE FLUSH WITH THE EDGE OF THE SIDEWALK.
5. ALL PUSH BUTTONS SHALL BE APS.
6. THIS LOCATION HAS BEEN DESIGNED TO BE ADA COMPLIANT. ANY DEVIATION FROM THIS PLAN FOR THE POSTS THAT HAVE PEDESTRIAN EQUIPMENT WILL HAVE TO BE APPROVED BY THE ENGINEER TO ENSURE ADA COMPLIANCE.

NOTES (CONTINUED)

7. THE EXISTING SERVICE METER SHALL BE RELOCATED TO THE PROPOSED GROUND MOUNTED SERVICE CABINET. THE EXISTING SERVICE METER HOUSING SHALL REMAIN AT THE EXISTING TRAFFIC SIGNAL CONTROLLER CABINET AND ALL HOLES BETWEEN THE EXISTING HOUSING AND THE EXISTING CABINET SHALL BE PLUGGED. THIS WORK SHALL BE INCLUDED IN THE PAY ITEM SERVICE INSTALLATION, GROUND MOUNTED, METERED.
8. PROPOSED CONDUIT SHALL BE SPLICED TO THE EXISTING CONDUIT AND EXTENDED VERTICALLY THROUGH THE PROPOSED FOUNDATION AT THE GROUND MOUNTED SERVICE LOCATION. THE COST OF THE CONDUIT SHALL BE INCLUDED IN THE COST OF CONCRETE FOUNDATION, TYPE A.

KimleyHorn

© 2021 KIMLEY-HORN AND ASSOCIATES, INC.
4001 WILSON D. ROAD, SUITE 600
WARREN, IL 6. 60555
PHONE: (847) 455-1100
WWW.KIMLEY-HORN.COM

USER NAME =	DESIGNED -	REVISED -
PLOT SCALE =	DRAWN -	REVISED -
PLOT DATE =	CHECKED -	REVISED -
	DATE -	REVISED -



**STATE OF ILLINOIS
DEPARTMENT OF TRANSPORTATION**

**TRAFFIC SIGNAL MODERNIZATION PLAN
IL 64 (NORTH AVE) AND KUHN RD**

SCALE: 1" = 20' SHEET OF SHEETS STA. TO STA.

F.A.P. RTE.	SECTION	COUNTY	TOTAL SHEETS	SHEET NO.
307	2020-263-SUR, SW&TS	DUPAGE	529	160
CONTRACT NO. 62N33				
ILLINOIS FED. AID PROJECT				

**TS 6445
IDOT TACTICS
FORMER EAGLE 2E**

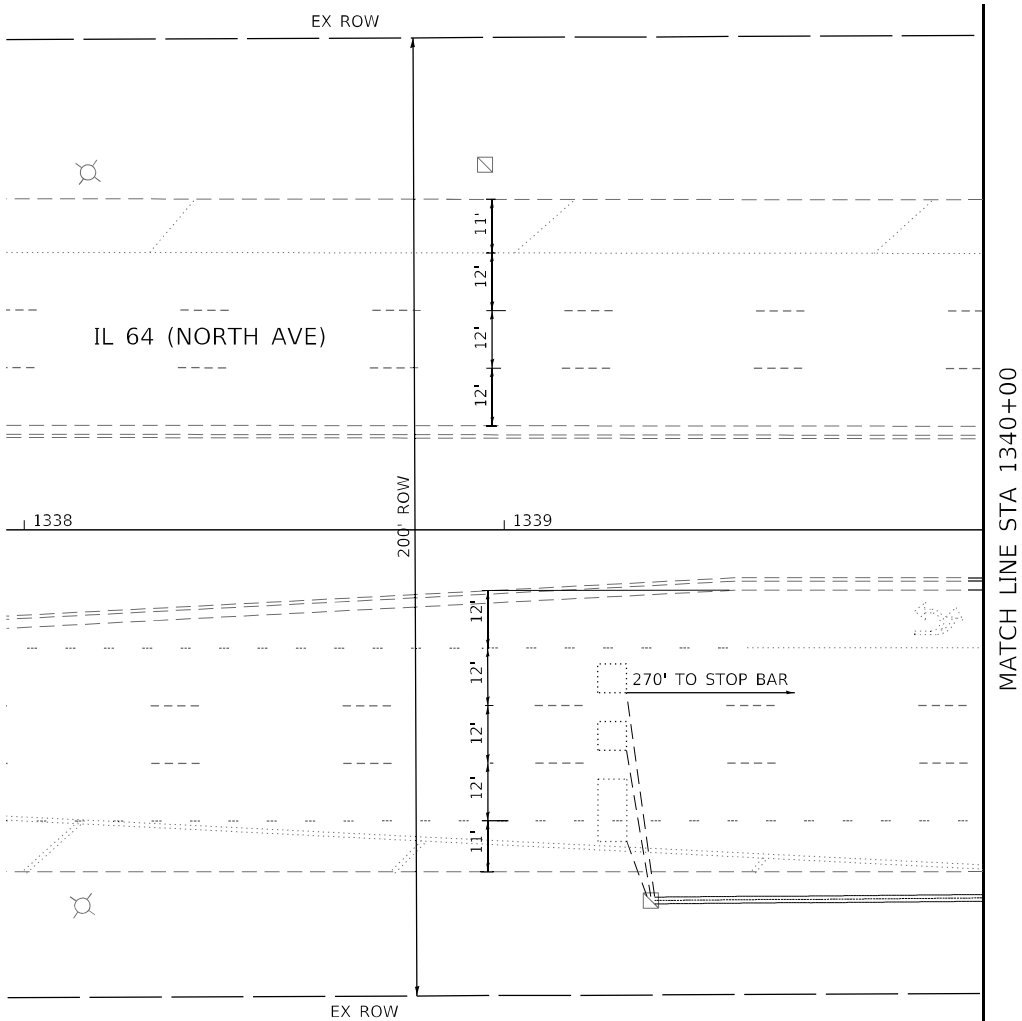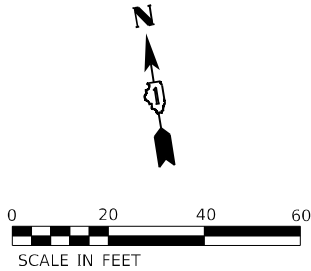

MODEL: Default
FILE: h:\mhc\projects\pva\bartley.com\h-pva-d1\Documents\01 Active Projects\MW\CL-S-160950\00 - IL 64\Phase 1\2 Design\CAD\Plan Streets\Signal\West Corridor_Signal\01081714-IL-64-KUH.dgn



USER NAME =	DESIGNED -	REVISED -
	DRAWN -	REVISED -
PLOT SCALE =	CHECKED -	REVISED -
PLOT DATE =	DATE -	REVISED -

STATE OF ILLINOIS
DEPARTMENT OF TRANSPORTATION

TRAFFIC SIGNAL MODERNIZATION PLAN
IL 64 (NORTH AVE) AND KUHN RD

SCALE: 1" = 20' SHEET OF SHEETS STA. TO STA.

F.A.P. RTE.	SECTION	COUNTY	TOTAL SHEETS	SHEET NO.
307	2020-263-SUR,SW&TS	DUPAGE	529	161
CONTRACT NO. 62N33				
ILLINOIS FED. AID PROJECT				


TS 6445
IDOT TACTICS
FORMER EAGLE 2E

SIGN PANEL – TYPE 1 OR TYPE 2

ALL DIMENSIONS ARE IN INCHES UNLESS OTHERWISE NOTED



DESIGN SERIES	AREA (SQ FT)	SIGN PANEL TYPE	SHEETING TYPE	QTY. REQUIRED
D	12.5	2	ZZ	2

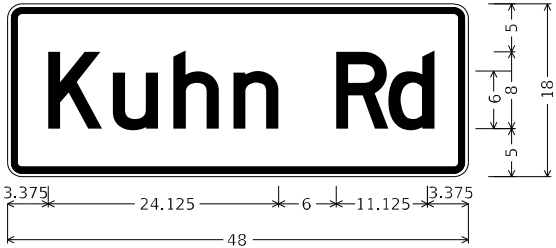

DESIGN SERIES	AREA (SQ FT)	SIGN PANEL TYPE	SHEETING TYPE	QTY. REQUIRED
D	6	1	ZZ	2

SCHEDULE OF QUANTITIES

ITEM DESCRIPTION	UNIT	QUANTITY
SIGN PANEL - TYPE 1	SQ FT	57
SIGN PANEL - TYPE 2	SQ FT	25
UNDERGROUND CONDUIT, GALVANIZED STEEL, 2" DIA.	FOOT	15
UNDERGROUND CONDUIT, GALVANIZED STEEL, 3" DIA.	FOOT	68
UNDERGROUND CONDUIT, GALVANIZED STEEL, 4" DIA.	FOOT	171
MAINTENANCE OF EXISTING TRAFFIC SIGNAL INSTALLATION	EACH	1
ELECTRIC CABLE IN CONDUIT, SIGNAL NO. 14 2C	FOOT	251
ELECTRIC CABLE IN CONDUIT, SIGNAL NO. 14 3C	FOOT	251
ELECTRIC CABLE IN CONDUIT, SIGNAL NO. 14 5C	FOOT	2540
ELECTRIC CABLE IN CONDUIT, SIGNAL NO. 14 7C	FOOT	1270
ELECTRIC CABLE IN CONDUIT, LEAD-IN, NO. 14 1 PAIR	FOOT	1488
ELECTRIC CABLE IN CONDUIT, SERVICE, NO. 6 2 C	FOOT	36
ELECTRIC CABLE IN CONDUIT, EQUIPMENT GROUNDING CONDUCTOR, NO. 6 1C	FOOT	275
TRAFFIC SIGNAL POST, GALVANIZED STEEL 16 FT.	EACH	2
STEEL COMBINATION MAST ARM ASSEMBLY AND POLE 64 FT.	EACH	1
STEEL COMBINATION MAST ARM ASSEMBLY AND POLE 66 FT.	EACH	1
CONCRETE FOUNDATION, TYPE A	FOOT	4
CONCRETE FOUNDATION, TYPE E 42-INCH DIAMETER	FOOT	46
DRILL EXISTING HANDHOLE	EACH	8
SIGNAL HEAD, LED, 1-FACE, 3-SECTION, MAST-ARM MOUNTED	EACH	10
SIGNAL HEAD, LED, 1-FACE, 3-SECTION, BRACKET MOUNTED	EACH	4
SIGNAL HEAD, LED, 1-FACE, 5-SECTION, BRACKET MOUNTED	EACH	4
SIGNAL HEAD, LED, 1-FACE, 5-SECTION, MAST-ARM MOUNTED	EACH	4
PEDESTRIAN SIGNAL HEAD, LED, 1-FACE, BRACKET MOUNTED WITH COUNTDOWN TIMER	EACH	1
TRAFFIC SIGNAL BACKPLATE, LOUVERED, FORMED PLASTIC	EACH	14
INDUCTIVE LOOP DETECTOR	EACH	5
* RELOCATE EXISTING EMERGENCY VEHICLE PRIORITY SYSTEM, DETECTOR UNIT	EACH	2
REMOVE ELECTRIC CABLE FROM CONDUIT	FOOT	6111
REMOVE EXISTING TRAFFIC SIGNAL EQUIPMENT	EACH	1
REMOVE EXISTING CONCRETE FOUNDATION	EACH	2
CLOSED CIRCUIT TELEVISION DOME CAMERA, HD	EACH	1
* EMERGENCY VEHICLE PRIORITY SYSTEM LINE SENSOR CABLE, NO. 20 3/C	FOOT	635
OUTDOOR RATED NETWORK CABLE	FOOT	293
SERVICE INSTALLATION, GROUND MOUNTED, METERED	EACH	1
REMOTE CONTROLLED VIDEO SYSTEM	EACH	1
LAYER II (DATALINK) SWITCH	EACH	1
TERMINATE FIBER IN CABINET	EACH	12
PEDESTRIAN SIGNAL POST, 10 FT.	EACH	1
TACTICS LICENSE EXPANSION	EACH	1
FULL-ACTUATED CONTROLLER IN EXISTING CABINET	EACH	1
REMOVE AND REPLACE BATTERIES FOR UNINTERRUPTABLE POWER SUPPLY, EXTENDED	EACH	1
FIBER OPTIC INTERCONNECT CENTER, 48 PORT	EACH	1
ACCESSIBLE PEDESTRIAN SIGNALS	EACH	1
CONCRETE FOUNDATION, TYPE A 12-INCH DIAMETER	FOOT	4
LED SIGNAL FACE, LENS COVER	EACH	22
VIDEO VEHICLE DETECTION SYSTEM, SINGLE APPROACH	EACH	2
CAMERA MOUNTING ASSEMBLY	EACH	1

* - 100% COST TO THE VILLAGE OF CAROL STREAM

TS 6445
IDOT TACTICS
FORMER EAGLE 2E

MODEL: Default
FILE: \\uslpc-prod\ut-pw-bentley.com\kth-gp-wd\Documents\01 Active Projects\MW-C\US-68959\00 - IL 64\Phase II\2 Design\CAD\Plan_Sheets\Sign\1-West_Corridor_Signs\BID\08171-1-IL-Rte-62_K4A.dgn

Kimley»Horn

© 2023 KIMLEY-HORN AND ASSOCIATES, INC.
4001 HWY 10, SUITE 600
WARREN, IL 60555
PHONE: 847.447.4555
WWW.KIMLEY-HORN.COM

USER NAME =	DESIGNED -	REVISED -
	DRAWN -	REVISED -
PLOT SCALE =	CHECKED -	REVISED -
PLOT DATE =	DATE -	REVISED -

STATE OF ILLINOIS
DEPARTMENT OF TRANSPORTATION



MAST ARM MOUNTED STREET NAME SIGNS AND
SCHEDULE OF QUANTITIES
IL 64 (NORTH AVE) AND KUHN RD

SCALE: N.T.S. SHEET OF SHEETS STA. TO STA.

F.A.P. RTE.	SECTION	COUNTY	TOTAL SHEETS	SHEET NO.
307	2020-263-SUR,SW&TS	DUPAGE	529	163
CONTRACT NO. 62N33				
ILLINOIS FED. AID PROJECT				

NOTES

- THE EXISTING TRAFFIC SIGNAL EQUIPMENT SHALL NOT BE REMOVED UNTIL THE PROPOSED TRAFFIC SIGNAL EQUIPMENT IS FULLY OPERATIONAL OR AS DIRECTED BY THE ENGINEER.
- ALL EXISTING TRAFFIC SIGNAL CABLE NO LONGER REQUIRED SHALL BE REMOVED.

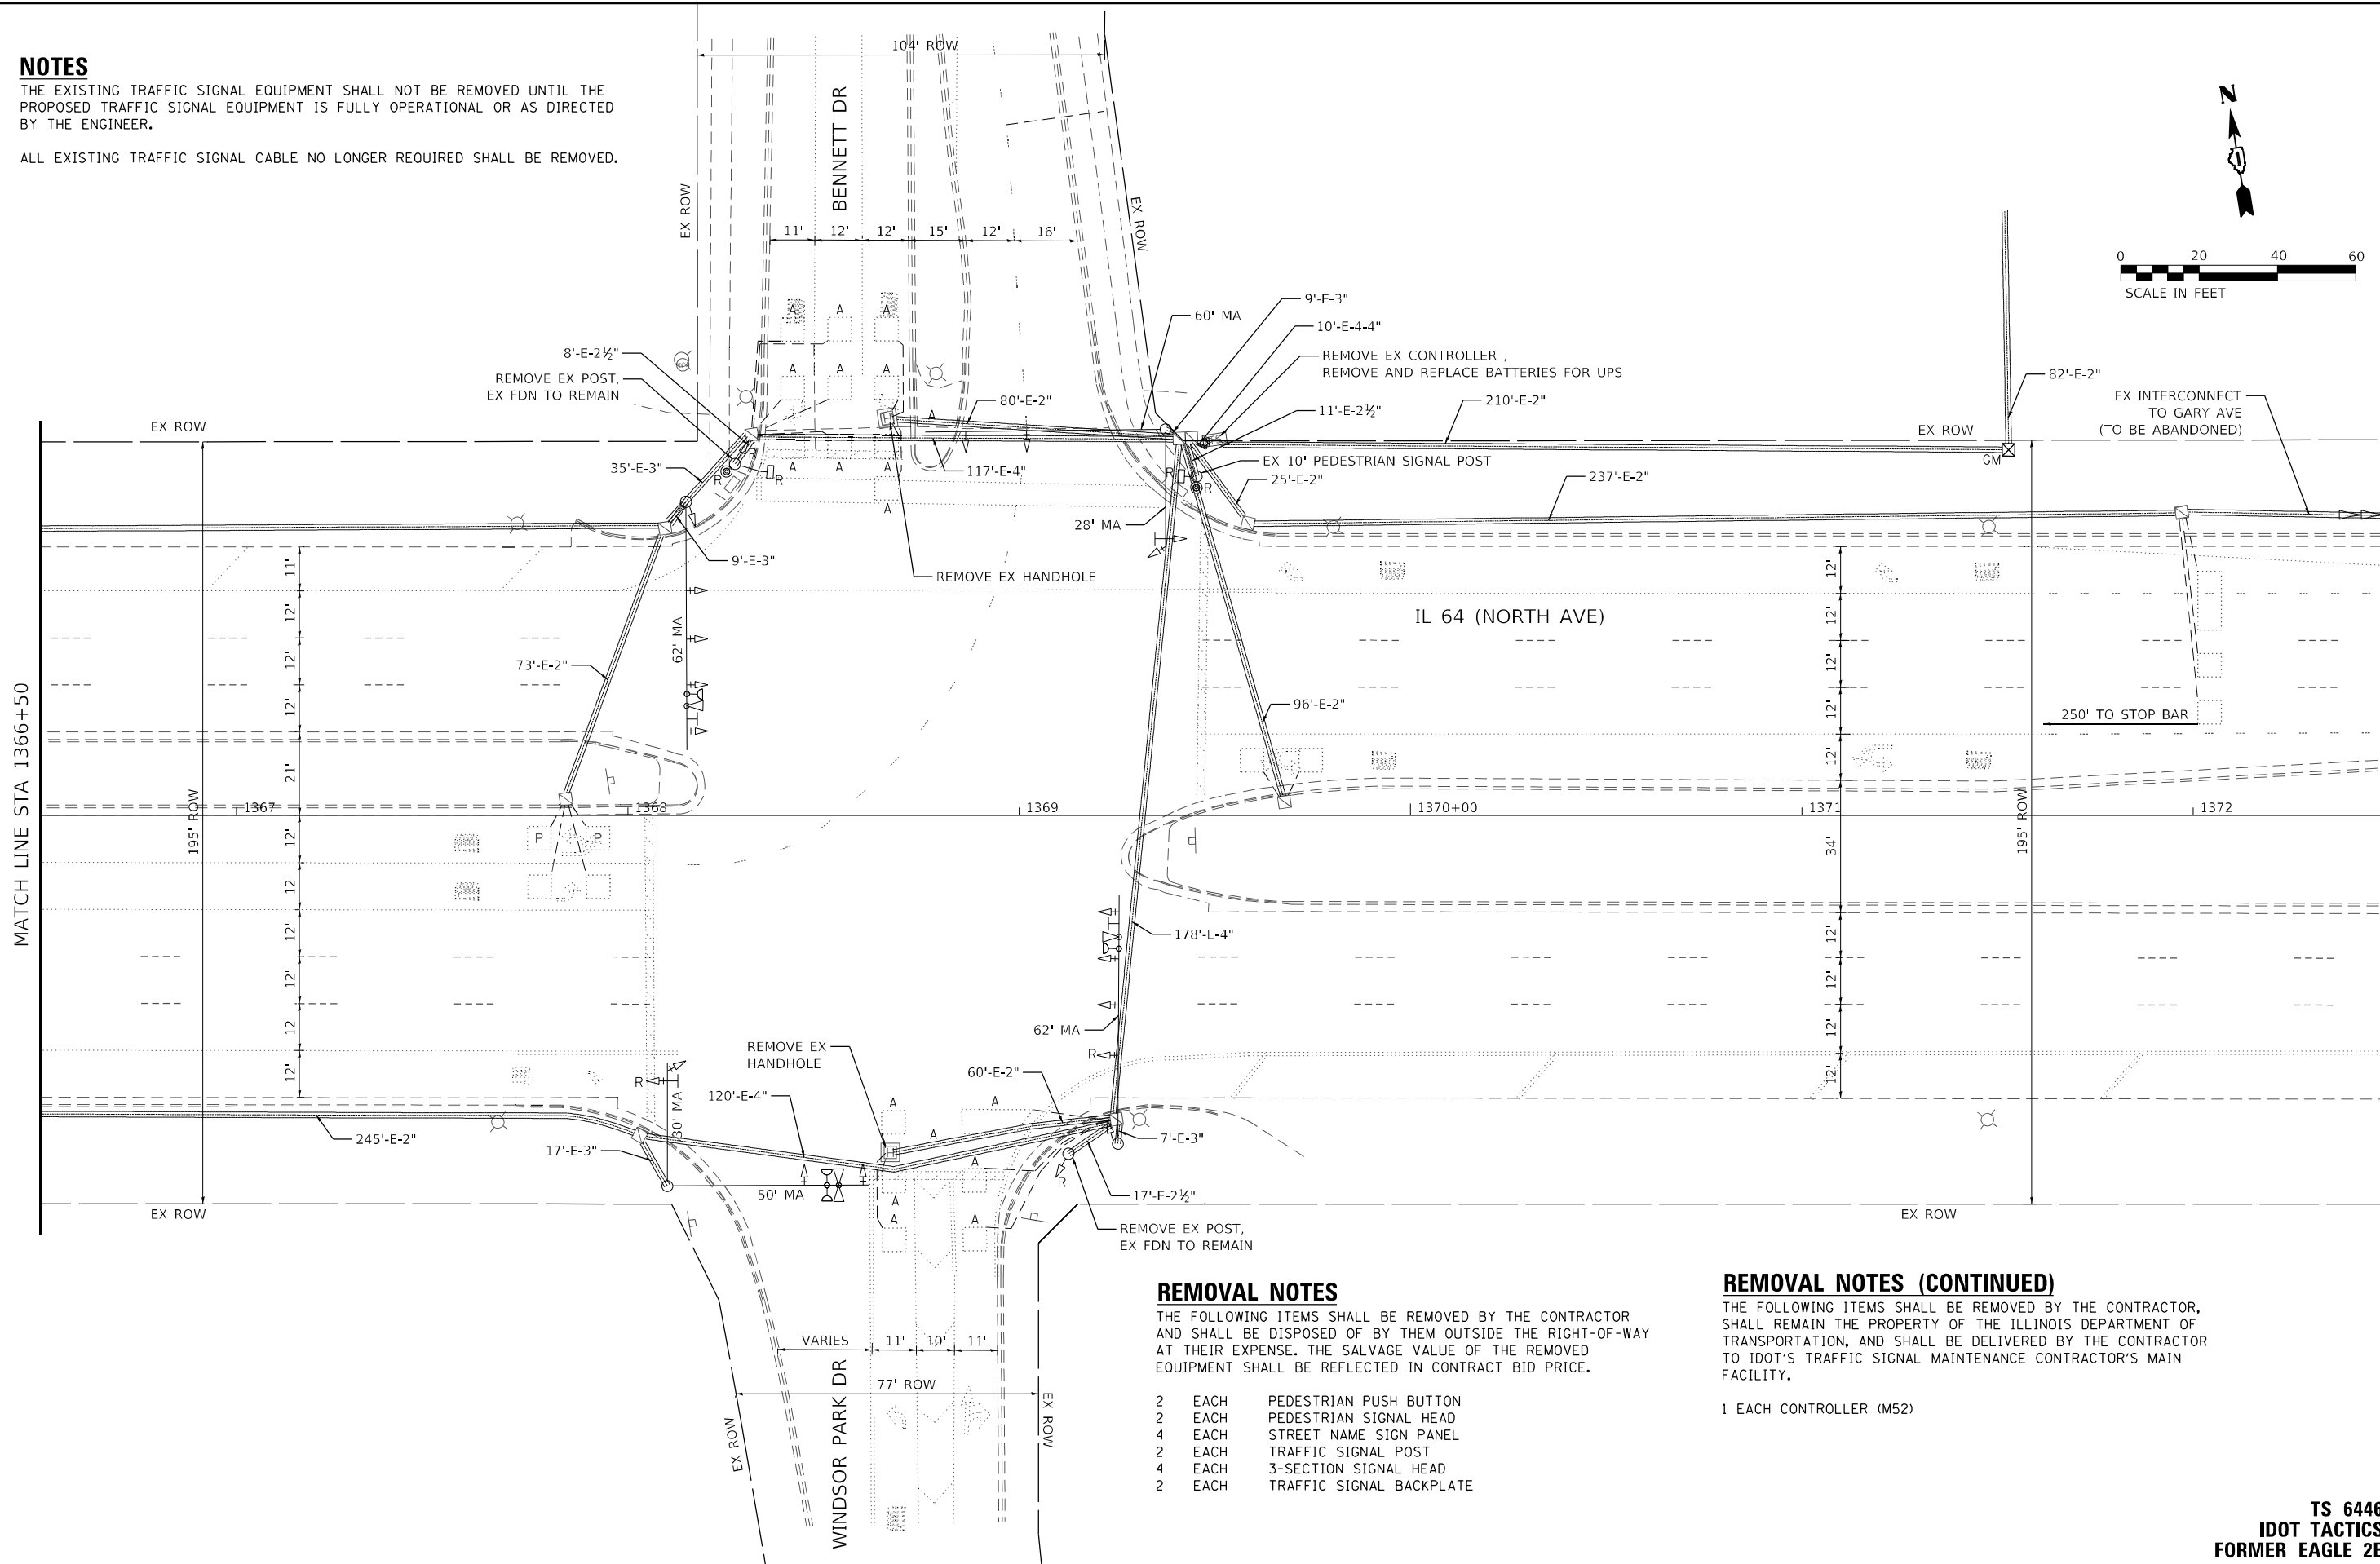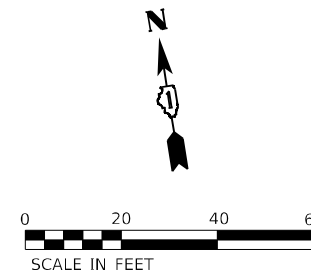

REMOVAL NOTES

THE FOLLOWING ITEMS SHALL BE REMOVED BY THE CONTRACTOR AND SHALL BE DISPOSED OF BY THEM OUTSIDE THE RIGHT-OF-WAY AT THEIR EXPENSE. THE SALVAGE VALUE OF THE REMOVED EQUIPMENT SHALL BE REFLECTED IN CONTRACT BID PRICE.

2	EACH	PEDESTRIAN PUSH BUTTON
2	EACH	PEDESTRIAN SIGNAL HEAD
4	EACH	STREET NAME SIGN PANEL
2	EACH	TRAFFIC SIGNAL POST
4	EACH	3-SECTION SIGNAL HEAD
2	EACH	TRAFFIC SIGNAL BACKPLATE

REMOVAL NOTES (CONTINUED)

THE FOLLOWING ITEMS SHALL BE REMOVED BY THE CONTRACTOR, SHALL REMAIN THE PROPERTY OF THE ILLINOIS DEPARTMENT OF TRANSPORTATION, AND SHALL BE DELIVERED BY THE CONTRACTOR TO IDOT'S TRAFFIC SIGNAL MAINTENANCE CONTRACTOR'S MAIN FACILITY.

1 EACH CONTROLLER (M52)

STATE OF ILLINOIS
DEPARTMENT OF TRANSPORTATION

TRAFFIC SIGNAL EQUIPMENT REMOVAL PLAN
IL 64 (NORTH AVE) AND BENNETT DR/WINDSOR PARK DR

SCALE: 1" = 20' SHEET OF SHEETS STA. TO STA.



F.A.P. RTE.	SECTION	COUNTY	TOTAL SHEETS	SHEET NO.
307	2020-263-SUR,SW&TS	DUPAGE	529	164
CONTRACT NO. 62N33				
ILLINOIS FED. AID PROJECT				

TS 6446
IDOT TACTICS
FORMER EAGLE 2E

KimleyHorn

© 2021 KIMLEY-HORN AND ASSOCIATES, INC.
4001 WILMINGTON ROAD, SUITE 600
WARREN, ILL. 60555
PHONE: (847) 455-4555
WWW.KIMLEY-HORN.COM

USER NAME =	DESIGNED -	REVISED -
	DRAWN -	REVISED -
PLOT SCALE =	CHECKED -	REVISED -
PLOT DATE =	DATE -	REVISED -

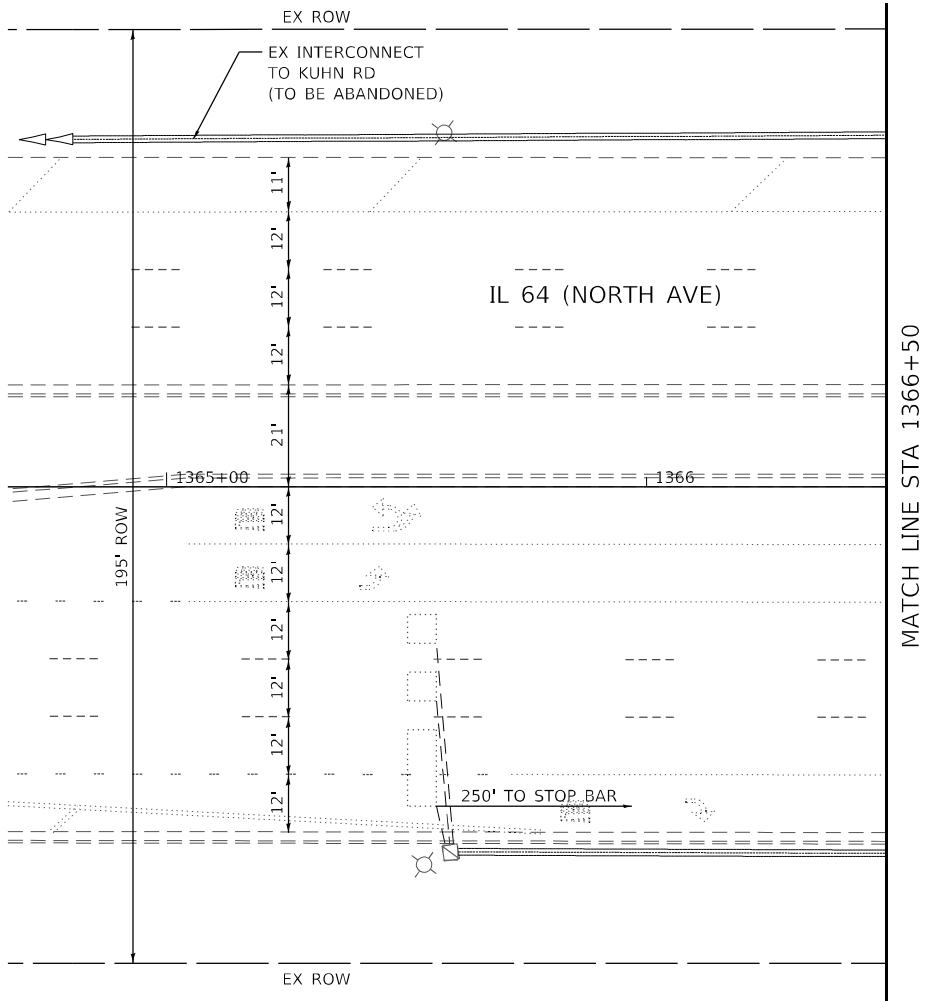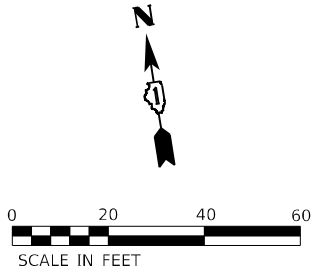

MODEL: Default
FILE NAME: p:\projects\pva\bartley.com\ts6446\ts6446.dgn
PROJECT: 2020-263-SUR, SW&TS
SHEET: 529 OF 165
CONTRACT NO. 62N33





USER NAME =	DESIGNED -	REVISED -
	DRAWN -	REVISED -
PLOT SCALE =	CHECKED -	REVISED -
PLOT DATE =	DATE -	REVISED -

STATE OF ILLINOIS
DEPARTMENT OF TRANSPORTATION

TRAFFIC SIGNAL EQUIPMENT REMOVAL PLAN IL 64 (NORTH AVE) AND BENNETT DR / WINDSOR PARK DR			
SCALE: 1" = 20'	SHEET	OF	SHEETS
STA.		TO STA.	

F.A.P. RTE.	SECTION	COUNTY	TOTAL SHEETS	SHEET NO.
307	2020-263-SUR, SW&TS	DUPAGE	529	165
CONTRACT NO. 62N33				
ILLINOIS		FED. AID PROJECT		

TS 6446
IDOT TACTICS
FORMER EAGLE 2E

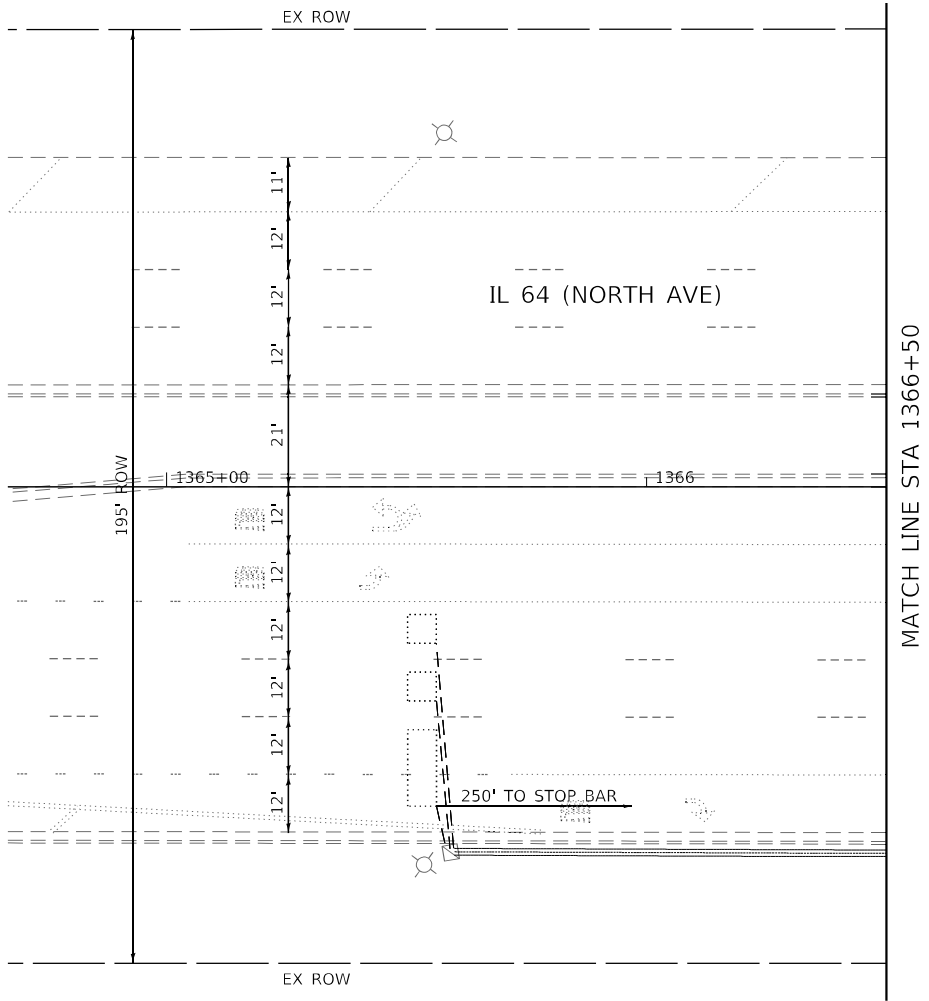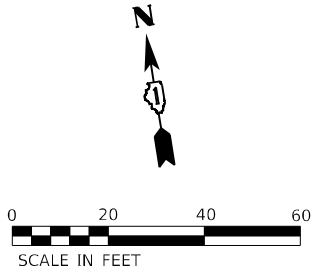

MODEL: Default
FILE NAME: p:\projects\pva\bartley.com\ts\ts-64\11\Documents\01 Active Projects\IMW\CHS-168950\00 - IL 64\Phase II\2 Design\CAD\Plan Sheets\Signal\West Corridor_Signal\01081714-IL-64-K4A.dgn



USER NAME =	DESIGNED -	REVISED -
	DRAWN -	REVISED -
PLOT SCALE =	CHECKED -	REVISED -
PLOT DATE =	DATE -	REVISED -

STATE OF ILLINOIS
DEPARTMENT OF TRANSPORTATION

TRAFFIC SIGNAL MODERNIZATION PLAN			
IL 64 (NORTH AVE) AND BENNETT DR/WINDSOR PARK DR			
SCALE: 1" = 20'	SHEET	OF	SHEETS
STA.		TO STA.	

F.A.P. RTE.	SECTION	COUNTY	TOTAL SHEETS	SHEET NO.
307	2020-263-SUR,SW&TS	DUPAGE	529	167
CONTRACT NO. 62N33				
ILLINOIS		FED. AID PROJECT		


TS 6446
IDOT TACTICS
FORMER EAGLE 2E

SIGN PANEL – TYPE 2


ALL DIMENSIONS ARE IN INCHES UNLESS OTHERWISE NOTED



DESIGN SERIES	AREA (SQ FT)	SIGN PANEL TYPE	SHEETING TYPE	QTY. REQUIRED
D	12.5	2	ZZ	2

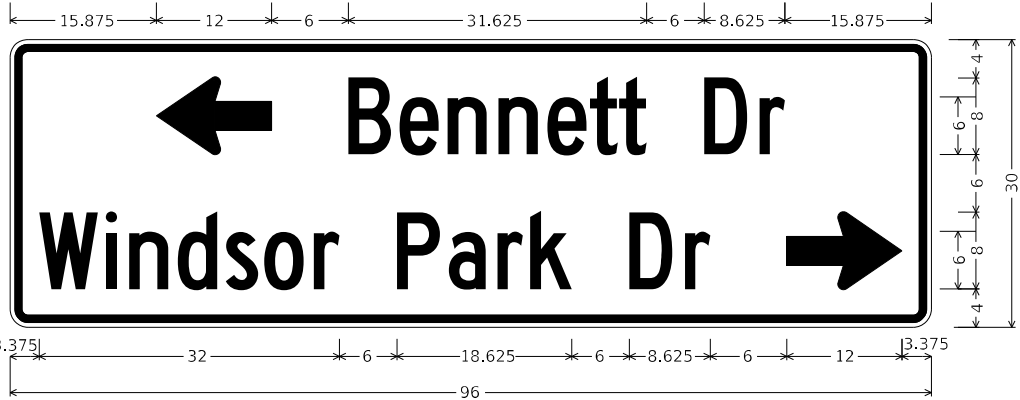

DESIGN SERIES	AREA (SQ FT)	SIGN PANEL TYPE	SHEETING TYPE	QTY. REQUIRED
C	20	2	ZZ	1

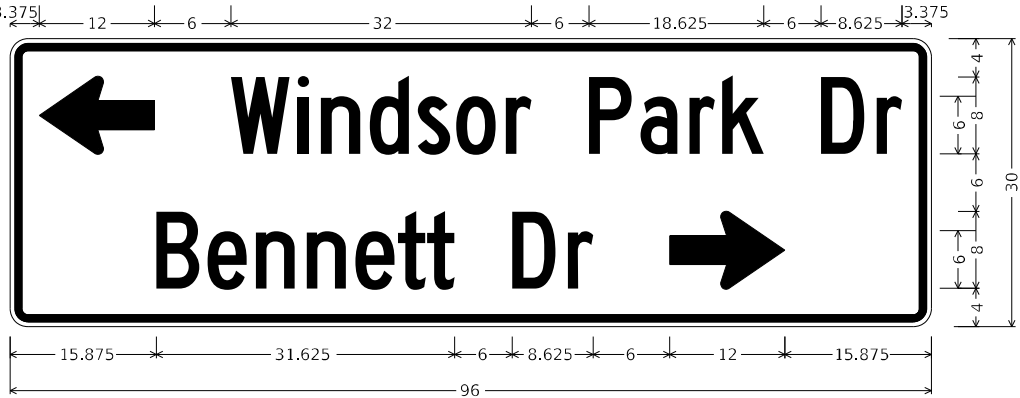

DESIGN SERIES	AREA (SQ FT)	SIGN PANEL TYPE	SHEETING TYPE	QTY. REQUIRED
C	20	2	ZZ	1

SCHEDULE OF QUANTITIES

ITEM DESCRIPTION	UNIT	QUANTITY
SIGN PANEL - TYPE 2	SQ FT	65
UNDERGROUND CONDUIT, GALVANIZED STEEL, 3" DIA.	FOOT	38
UNDERGROUND CONDUIT, GALVANIZED STEEL, 4" DIA.	FOOT	122
MAINTENANCE OF EXISTING TRAFFIC SIGNAL INSTALLATION	EACH	1
ELECTRIC CABLE IN CONDUIT, SIGNAL NO. 14 2C	FOOT	581
ELECTRIC CABLE IN CONDUIT, SIGNAL NO. 14 3C	FOOT	581
ELECTRIC CABLE IN CONDUIT, SIGNAL NO. 14 7C	FOOT	417
ELECTRIC CABLE IN CONDUIT, EQUIPMENT GROUNDING CONDUCTOR, NO. 6 1C	FOOT	160
TRAFFIC SIGNAL POST, GALVANIZED STEEL 16 FT.	EACH	2
DRILL EXISTING HANDHOLE	EACH	4
SIGNAL HEAD, LED, 1-FACE, 3-SECTION, BRACKET MOUNTED	EACH	2
SIGNAL HEAD, LED, 1-FACE, 5-SECTION, MAST-ARM MOUNTED	EACH	2
PEDESTRIAN SIGNAL HEAD, LED, 1-FACE, BRACKET MOUNTED WITH COUNTDOWN TIMER	EACH	4
TRAFFIC SIGNAL BACKPLATE, LOUVERED, FORMED PLASTIC	EACH	2
REMOVE ELECTRIC CABLE FROM CONDUIT	FOOT	1739
REMOVE EXISTING TRAFFIC SIGNAL EQUIPMENT	EACH	1
REMOVE EXISTING HANDHOLE	EACH	2
CLOSED CIRCUIT TELEVISION DOME CAMERA, HD	EACH	1
OUTDOOR RATED NETWORK CABLE	FOOT	94
REMOTE CONTROLLED VIDEO SYSTEM	EACH	1
LAYER II (DATALINK) SWITCH	EACH	1
TERMINATE FIBER IN CABINET	EACH	12
PEDESTRIAN SIGNAL POST, 10 FT.	EACH	1
PEDESTRIAN SIGNAL POST, 5 FT.	EACH	1
TACTICS LICENSE EXPANSION	EACH	1
FULL-ACTUATED CONTROLLER IN EXISTING CABINET	EACH	1
REMOVE AND REPLACE BATTERIES FOR UNINTERRUPTABLE POWER SUPPLY, EXTENDED	EACH	1
FIBER OPTIC INTERCONNECT CENTER, 48 PORT	EACH	1
ACCESSIBLE PEDESTRIAN SIGNALS	EACH	4
CONCRETE FOUNDATION, TYPE A 12-INCH DIAMETER	FOOT	8
LED SIGNAL MODULE REPLACEMENT	EACH	60
LED SIGNAL FACE, LENS COVER	EACH	20
VIDEO VEHICLE DETECTION SYSTEM, SINGLE APPROACH	EACH	2
CAMERA MOUNTING ASSEMBLY	EACH	1

TS 6446
IDOT TACTICS
FORMER EAGLE 2E

MODEL: Default
FILE: I:\MISC_projects\pvt_bentley.com\ktp\p4\1\Documents\01_Active_Projects\MW-Ch-S-16895\000 - IL_64\Phase_III\2_Design\CAD\Plan_Sheets\Sign\West_Corridor_Signals\ID108171-1-Int-68_K4A.dgn

Kimley»Horn

© 2023 KIMLEY-HORN AND ASSOCIATES, INC.
4001 HWY 10, SUITE 400
WARREN, IL 60555
PHONE: 847.447.4555
WWW.KH-IL.COM

USER NAME =
PLOT SCALE =
PLOT DATE =

DESIGNED -
DRAWN -
CHECKED -
DATE -

REVISED -
REVISED -
REVISED -
REVISED -

STATE OF ILLINOIS
DEPARTMENT OF TRANSPORTATION

SCHEDULE OF QUANTITIES
IL 64 (NORTH AVE) AND BENNETT DR/WINDSOR PARK DR

SCALE: N.T.S. SHEET OF SHEETS STA. TO STA.

F.A.P.
RTE.
307

SECTION
2020-263-SUR,SW&TS

COUNTY
DUPAGE

TOTAL
SHEETS
529


SHEET
NO.
169

CONTRACT NO. 62N33

ILLINOIS FED. AID PROJECT

NOTES

1. THE EXISTING TRAFFIC SIGNAL EQUIPMENT SHALL NOT BE REMOVED UNTIL THE PROPOSED TRAFFIC SIGNAL EQUIPMENT IS FULLY OPERATIONAL OR AS DIRECTED BY THE ENGINEER.
2. ALL EXISTING TRAFFIC SIGNAL CABLE NO LONGER REQUIRED SHALL BE REMOVED.

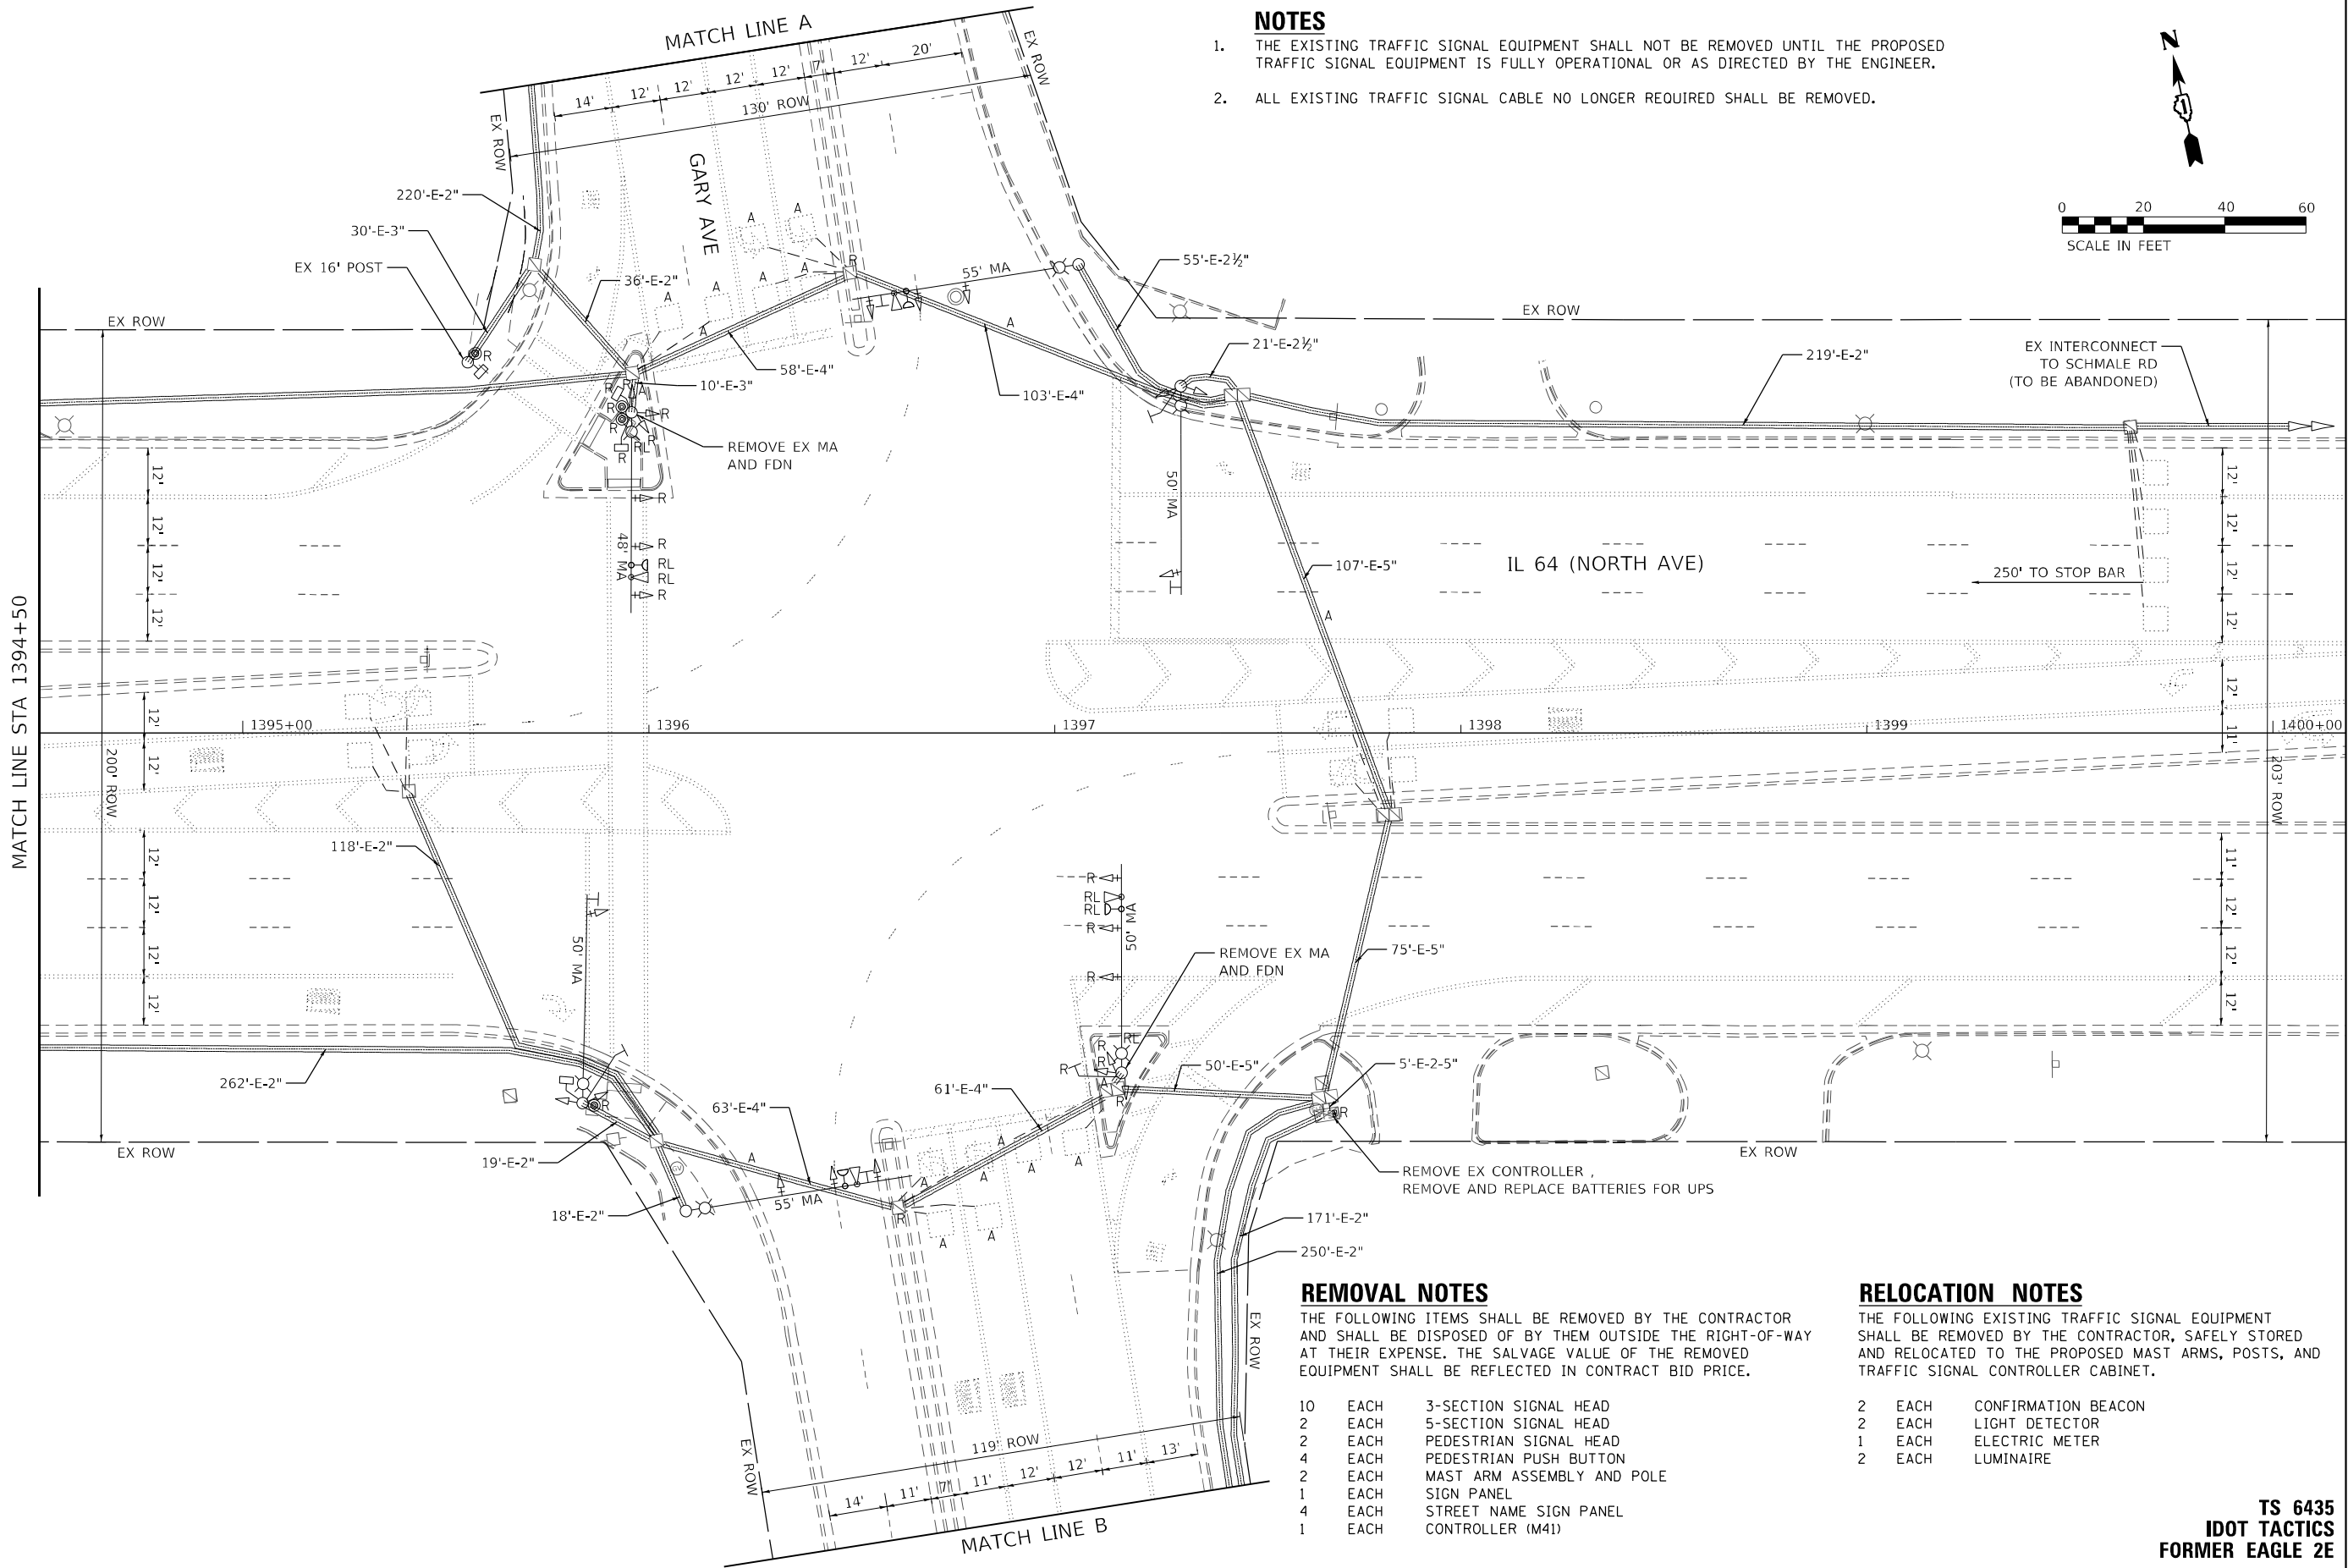

REMOVAL NOTES

THE FOLLOWING ITEMS SHALL BE REMOVED BY THE CONTRACTOR AND SHALL BE DISPOSED OF BY THEM OUTSIDE THE RIGHT-OF-WAY AT THEIR EXPENSE. THE SALVAGE VALUE OF THE REMOVED EQUIPMENT SHALL BE REFLECTED IN CONTRACT BID PRICE.

10	EACH	3-SECTION SIGNAL HEAD
2	EACH	5-SECTION SIGNAL HEAD
2	EACH	PEDESTRIAN SIGNAL HEAD
4	EACH	PEDESTRIAN PUSH BUTTON
2	EACH	MAST ARM ASSEMBLY AND POLE
1	EACH	SIGN PANEL
4	EACH	STREET NAME SIGN PANEL
1	EACH	CONTROLLER (M41)

RELOCATION NOTES

THE FOLLOWING EXISTING TRAFFIC SIGNAL EQUIPMENT SHALL BE REMOVED BY THE CONTRACTOR, SAFELY STORED AND RELOCATED TO THE PROPOSED MAST ARMS, POSTS, AND TRAFFIC SIGNAL CONTROLLER CABINET.

2	EACH	CONFIRMATION BEACON
2	EACH	LIGHT DETECTOR
1	EACH	ELECTRIC METER
2	EACH	LUMINAIRE

TS 6435
IDOT TACTICS
FORMER EAGLE 2E

KimleyHorn

© 2021 KIMLEY-HORN AND ASSOCIATES, INC.
4001 WILMINGTON ROAD, SUITE 600
WARREN, ILL. 60555
PHONE: (847) 455-4555
WWW.KIMLEY-HORN.COM





USER NAME =	DESIGNED -	REVISED -
	DRAWN -	REVISED -
PLOT SCALE =	CHECKED -	REVISED -
PLOT DATE =	DATE -	REVISED -

STATE OF ILLINOIS
DEPARTMENT OF TRANSPORTATION

TRAFFIC SIGNAL EQUIPMENT REMOVAL PLAN
IL 64 (NORTH AVE) AND GARY AVE

SCALE: 1" = 20' SHEET OF SHEETS STA. TO STA.


F.A.P. RTE.	SECTION	COUNTY	TOTAL SHEETS	SHEET NO.
307	2020-263-SUR, SW&TS	DUPAGE	529	170
				CONTRACT NO. 62N33
		ILLINOIS	FED. AID PROJECT	

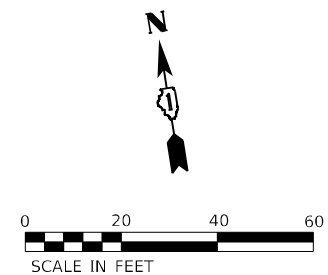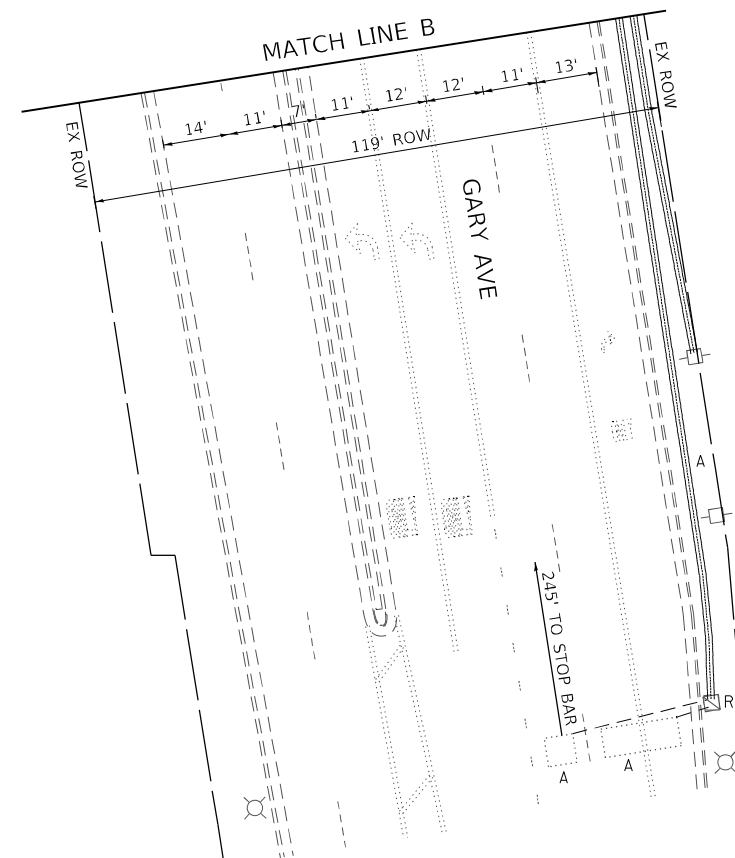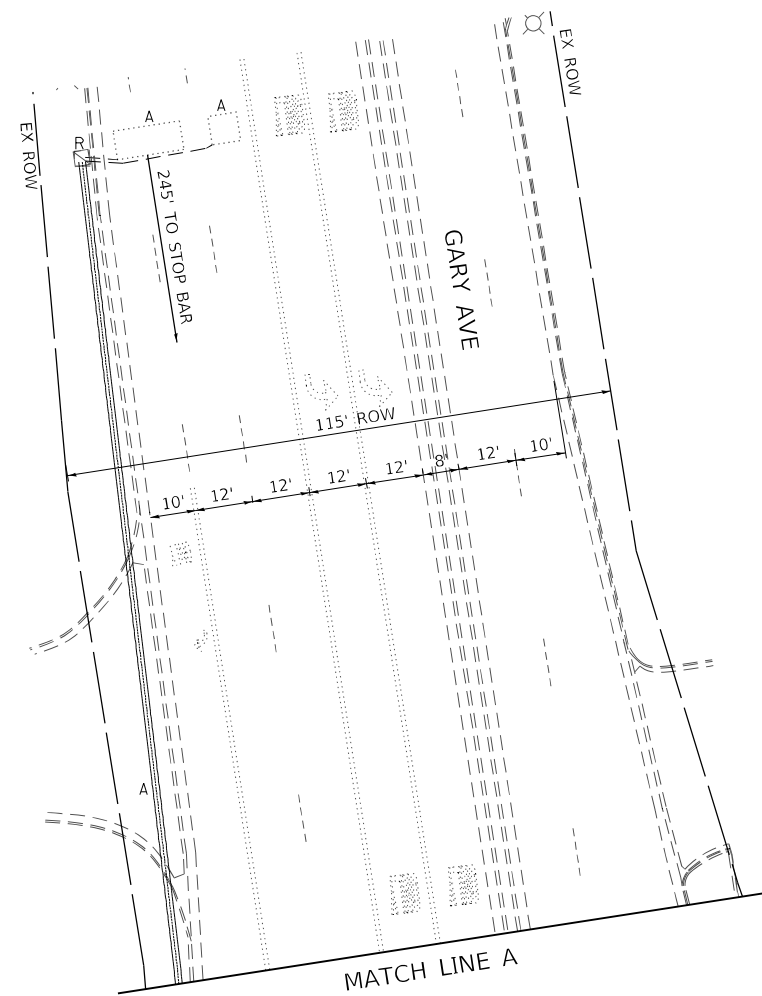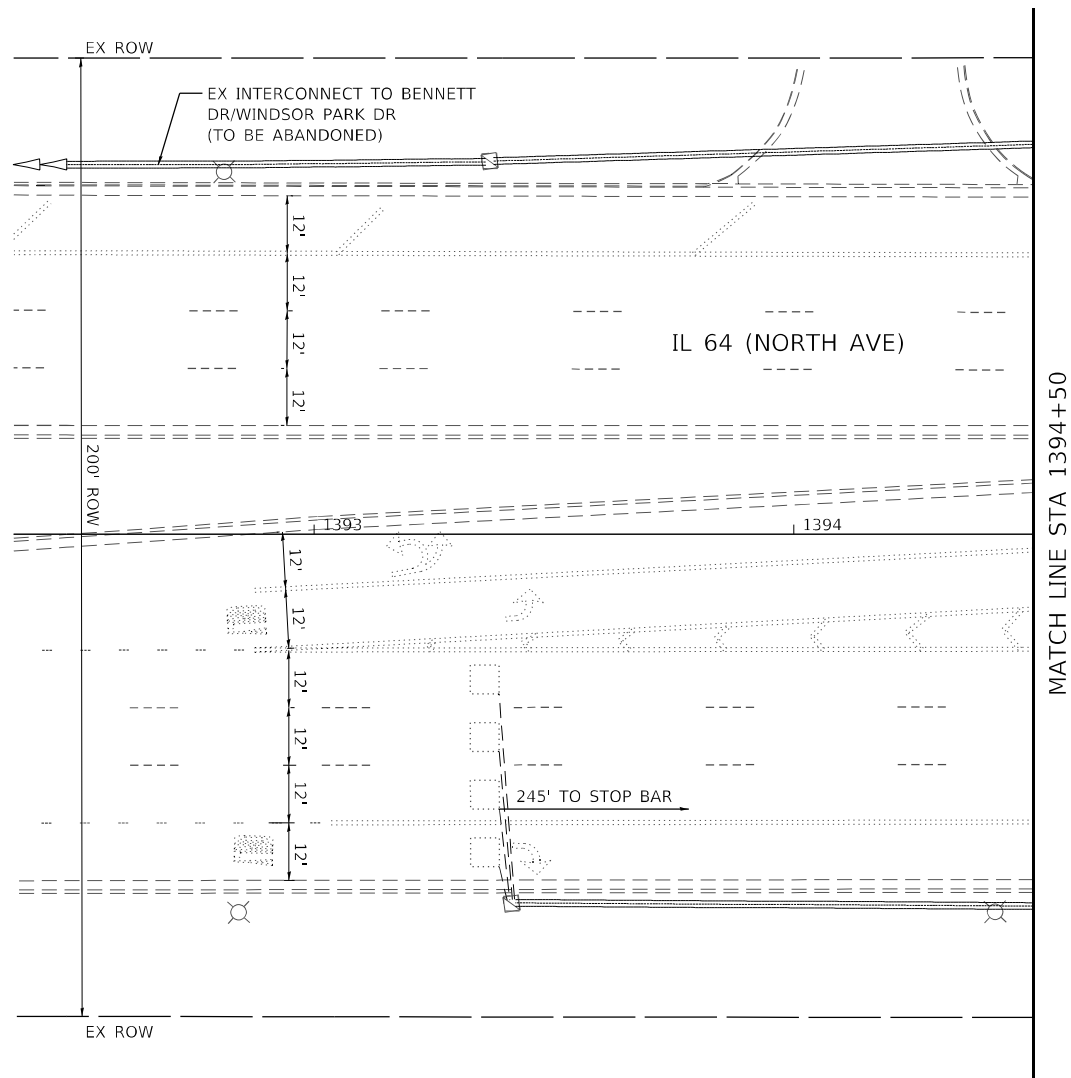


TS 6435
IDOT TACTICS
FORMER EAGLE 2E

 © 2022 KIMLEY-HORN AND ASSOCIATES, INC. 4001 WILSON, D. ROAD, SUITE 600 VANDERBILT, ILL. 6. 60555 PHONE: 630.440.4000 WWW.KIMLEY-HORN.COM	USER NAME =	DESIGNED -	REVISED -	STATE OF ILLINOIS DEPARTMENT OF TRANSPORTATION	TRAFFIC SIGNAL EQUIPMENT REMOVAL PLAN IL 64 (NORTH AVE) AND GARY AVE					F.A.P. RTE.	SECTION	COUNTY	TOTAL SHEETS	SHEET NO.
		DRAWN -	REVISED -							307	2020-263-SUR, SW&TS	DUPAGE	529	171
	PLOT SCALE =	CHECKED -	REVISED -		SCALE: 1" = 20' SHEET OF SHEETS STA. TO STA.					CONTRACT NO. 62N33				
	PLOT DATE =	DATE -	REVISED -											

TEMPORARY CONTROLLER SEQUENCE

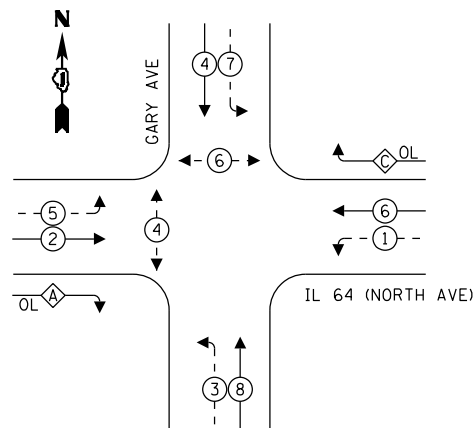


LEGEND:

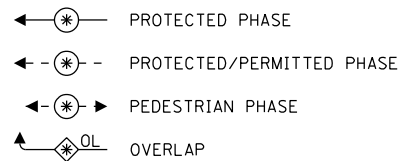

OVERLAP LETTER		PERMISSIVE PHASE		PROTECTED PHASE
A	=	2	+	3
C	=	6	+	7

TEMPORARY EMERGENCY VEHICLE PREEMPTION SEQUENCE

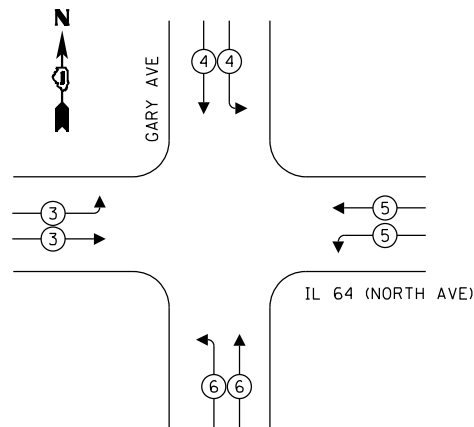

TRAFFIC SIGNAL ELECTRICAL SERVICE REQUIREMENTS

TYPE	QUANTITY	UNIT WATTAGE	TOTAL WATTAGE
SIGNAL HEAD 1 OR 3-SECTION	-	11	-
4-SECTION	-	14	-
5-SECTION	-	13	-
PROGRAMMABLE 3-SECTION	-	22	-
4-SECTION	-	32	-
5-SECTION	-	28	-
PEDESTRIAN SIGNAL	-	15	-
CONTROLLER	1	150	150
MASTER CONTROLLER	-	100	-
UPS	1	25	25
DETECTION VIDEO	-	20	-
BLANK-OUT SIGN	-	25	-
NETWORK SWITCH LAYER II OR III	1	35	35
CELLULAR MODEM	-	15	-
TOTAL UPS SIZING			210
UPS CHARGING	1	225	225
BATTERY HEATER MAT	1	180	180
CABINET HEATER	1	200	200
FLASHER	-	15	-
LED STREET NAME SIGN	-	120	-
LUMINAIRE	-	240	-
TOTAL SERVICE WIRE SIZING			815

NOTES


1. ONLY RED SIGNAL FACES SHALL HAVE A LENS COVER INSTALLED.

ENERGY COSTS TO:
ILLINOIS DEPARTMENT OF TRANSPORTATION
201 W CENTER CT
SCHAUMBURG, IL 60196

ENERGY SUPPLY: COMPANY: COMED
PHONE: (866) 639-3532
ACCOUNT NUMBER: 20051-18081

LEGEND:

L = LED LAMP MODULE REPLACEMENT
RL = RELOCATE
* = ROADWAY LIGHTING CABLE

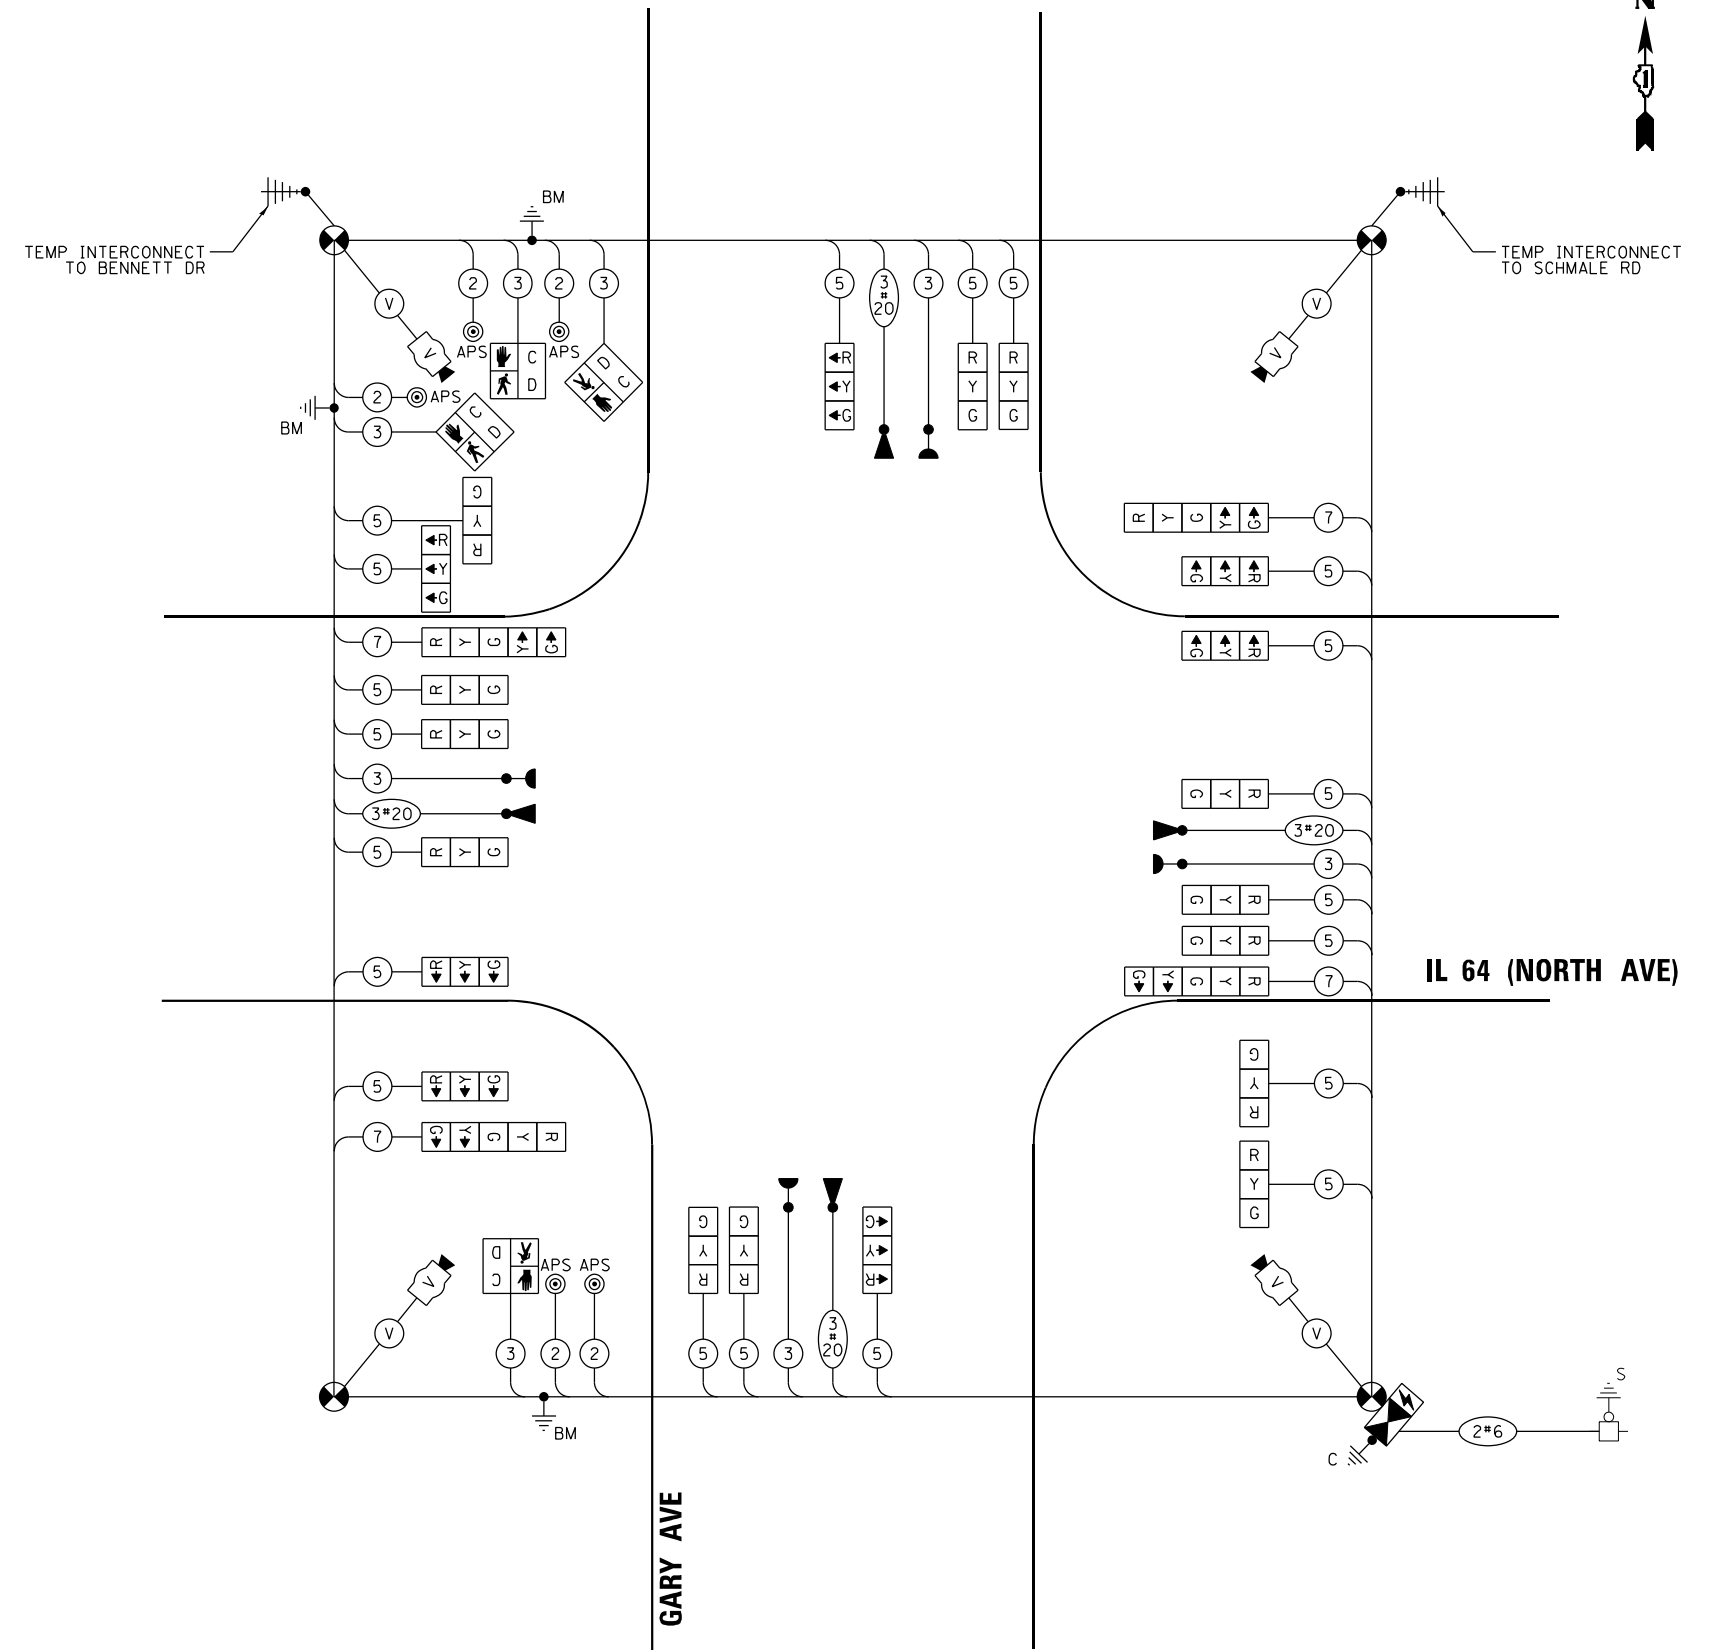

CABLE PLAN

(NOT TO SCALE)

TS 6435
IDOT TACTICS
FORMER EAGLE 2E

F.A.P. RTE.	SECTION	COUNTY	TOTAL SHEETS	SHEET NO.
307	2020-263-SUR, SW&TS	DUPAGE	529	173
		CONTRACT NO. 62N33		
		ILLINOIS FED. AID PROJECT		

STATE OF ILLINOIS
DEPARTMENT OF TRANSPORTATION

**TEMPORARY CABLE PLAN, PHASE DESIGNATION DIAGRAM, AND
EMERGENCY VEHICLE PREEMPTION SEQUENCE
IL 64 (NORTH AVE) AND GARY AVE**

SCALE: N.T.S.	SHEET	OF	SHEETS	STA.	TO STA.
---------------	-------	----	--------	------	---------

Kimley»Horn

© 2023 KIMLEY-HORN AND ASSOCIATES, INC.
4201 WILMFIELD ROAD, SUITE 600
WARRENVILLE, IL 60555
PHONE: 630-487-5550
WWW.KIMLEY-HORN.COM

USER NAME	=	
PLOT SCALE	=	
PLOT DATE	=	

DESIGNED -
DRAWN -
CHECKED -
DATE -

REVISED	-
REVISED	-
REVISED	-
REVISED	-

MODEL: Default
FILE NAME: pw:\k-f-pw.bentlev.com\kh-pw-01\Documents\01 Active Projects\MW-CHS-169959\100 - IL 64\Phase II\2 Design\CAD\plan Sheets\Signals\West Corridor Signals\010812 L-sht-ts-72 KHA.dgn

MODEL: Default
FILE: I:\Users\paul.bentley\OneDrive\Documents\01 Active Projects\IMW\CHS-168959\100 - IL 64\Phase 1\12 Design\CAD\Plan_Signals\SignalWest Corridor_Signals\108171-1-14-14-14-73_KIM.dgn

NOTES

1. ALL PROPOSED TRAFFIC SIGNAL CABLE SHALL BE ROUTED THROUGH THE PROPOSED CONDUIT.
2. A SEPARATE LEAD-IN CABLE SHALL BE INSTALLED FOR THE DETECTOR LOOPS ON IL 64 (NORTH AVE).
3. THERE SHALL BE A MINIMUM OF 4' SIDEWALK CLEARANCE IN FRONT/BEHIND OF THE TRAFFIC SIGNAL FOUNDATIONS TO BE ADA COMPLIANT.
4. THE SIDEWALK CURBS ON ALL QUADRANTS SHALL BE CUT SO THAT THE POST AND MAST ARM FOUNDATIONS ARE FLUSH WITH THE EDGE OF THE SIDEWALK.
5. ALL PUSH BUTTONS SHALL BE APS.
6. THIS LOCATION HAS BEEN DESIGNED TO BE ADA COMPLIANT. ANY DEVIATION FROM THIS PLAN FOR THE POSTS THAT HAVE PEDESTRIAN EQUIPMENT WILL HAVE TO BE APPROVED BY THE ENGINEER TO ENSURE ADA COMPLIANCE.
7. CONTRACTOR SHALL VERIFY THAT THE PLACEMENT OF THE PROPOSED SIGNAL EQUIPMENT ADJACENT TO EXISTING RAMPS MEET ADA REQUIREMENTS. THE ENGINEER SHALL APPROVE THE PROPOSED LOCATIONS OF THE SIGNAL EQUIPMENT BEFORE INSTALLATION.

KimleyHorn

© 2023 KIMLEY-HORN AND ASSOCIATES, INC.
4001 WILHELM D. ROAD, SUITE 600
WARREN, ILL. 60555
PHONE: (815) 474-4555
WWW.KIMLEY-HORN.COM

USER NAME =	DESIGNED -	REVISED -
	DRAWN -	REVISED -
PLOT SCALE =	CHECKED -	REVISED -
PLOT DATE =	DATE -	REVISED -

STATE OF ILLINOIS
DEPARTMENT OF TRANSPORTATION

TRAFFIC SIGNAL MODERNIZATION PLAN
IL 64 (NORTH AVE) AND GARY AVE

SCALE: 1" = 20' SHEET OF SHEETS STA. TO STA.


LEFT ON
GREEN
ARROW
ONLY

R10-5
30" X 36"


TS 6435
IDOT TACTICS
FORMER EAGLE 2E

F.A.P. RTE.	SECTION	COUNTY	TOTAL SHEETS	SHEET NO.
307	2020-263-SUR, SW&TS	DUPAGE	529	174
CONTRACT NO. 62N33				
ILLINOIS FED. AID PROJECT				

EXISTING AND PROPOSED CONTROLLER SEQUENCE

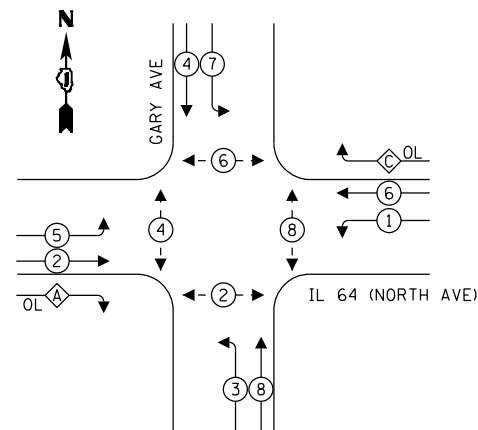


LEGEND:

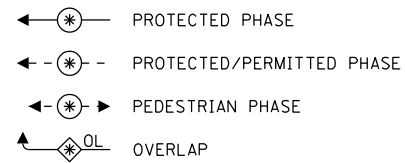

OVERLAP LETTER		PERMISSIVE PHASE		PROTECTED PHASE
A	=	2	+	3
C	=	6	+	7

EXISTING AND PROPOSED EMERGENCY VEHICLE PREEMPTION SEQUENCE

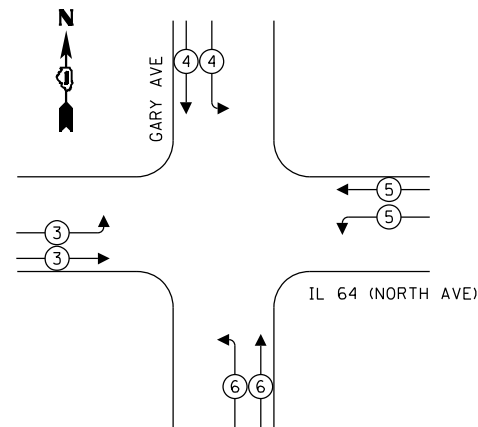

TRAFFIC SIGNAL ELECTRICAL SERVICE REQUIREMENTS

TYPE	QUANTITY	UNIT WATTAGE	TOTAL WATTAGE
SIGNAL HEAD 1 OR 3-SECTION	-	11	-
4-SECTION	-	14	-
5-SECTION	-	13	-
PROGRAMMABLE 3-SECTION	-	22	-
4-SECTION	-	32	-
5-SECTION	-	28	-
PEDESTRIAN SIGNAL	-	15	-
CONTROLLER	1	150	150
MASTER CONTROLLER	-	100	-
UPS	1	25	25
DETECTION RADAR OR VIDEO	-	20	-
BLANK-OUT SIGN	-	25	-
NETWORK SWITCH II OR III	1	35	35
CELLULAR MODEM	-	15	-
TOTAL UPS SIZING			210
UPS CHARGING	1	225	225
BATTERY HEATER MAT	1	180	180
CABINET HEATER	1	200	200
FLASHER	-	15	-
LED STREET NAME SIGN	-	120	-
LUMINAIRE	-	240	-
TOTAL SERVICE WIRE SIZING			815

ENERGY COSTS TO: ILLINOIS DEPARTMENT OF TRANSPORTATION 201 W CENTER CT SCHAUMBURG, IL 60196
--


ENERGY SUPPLY: COMPANY: COMED
PHONE: (866) 639-3532
ACCOUNT NUMBER: 20051-18081

LEGEND:

L = LED LAMP MODULE REPLACEMENT
RL = RELOCATE
* = ROADWAY LIGHTING CABLE

CABLE PLAN

(NOT TO SCALE)

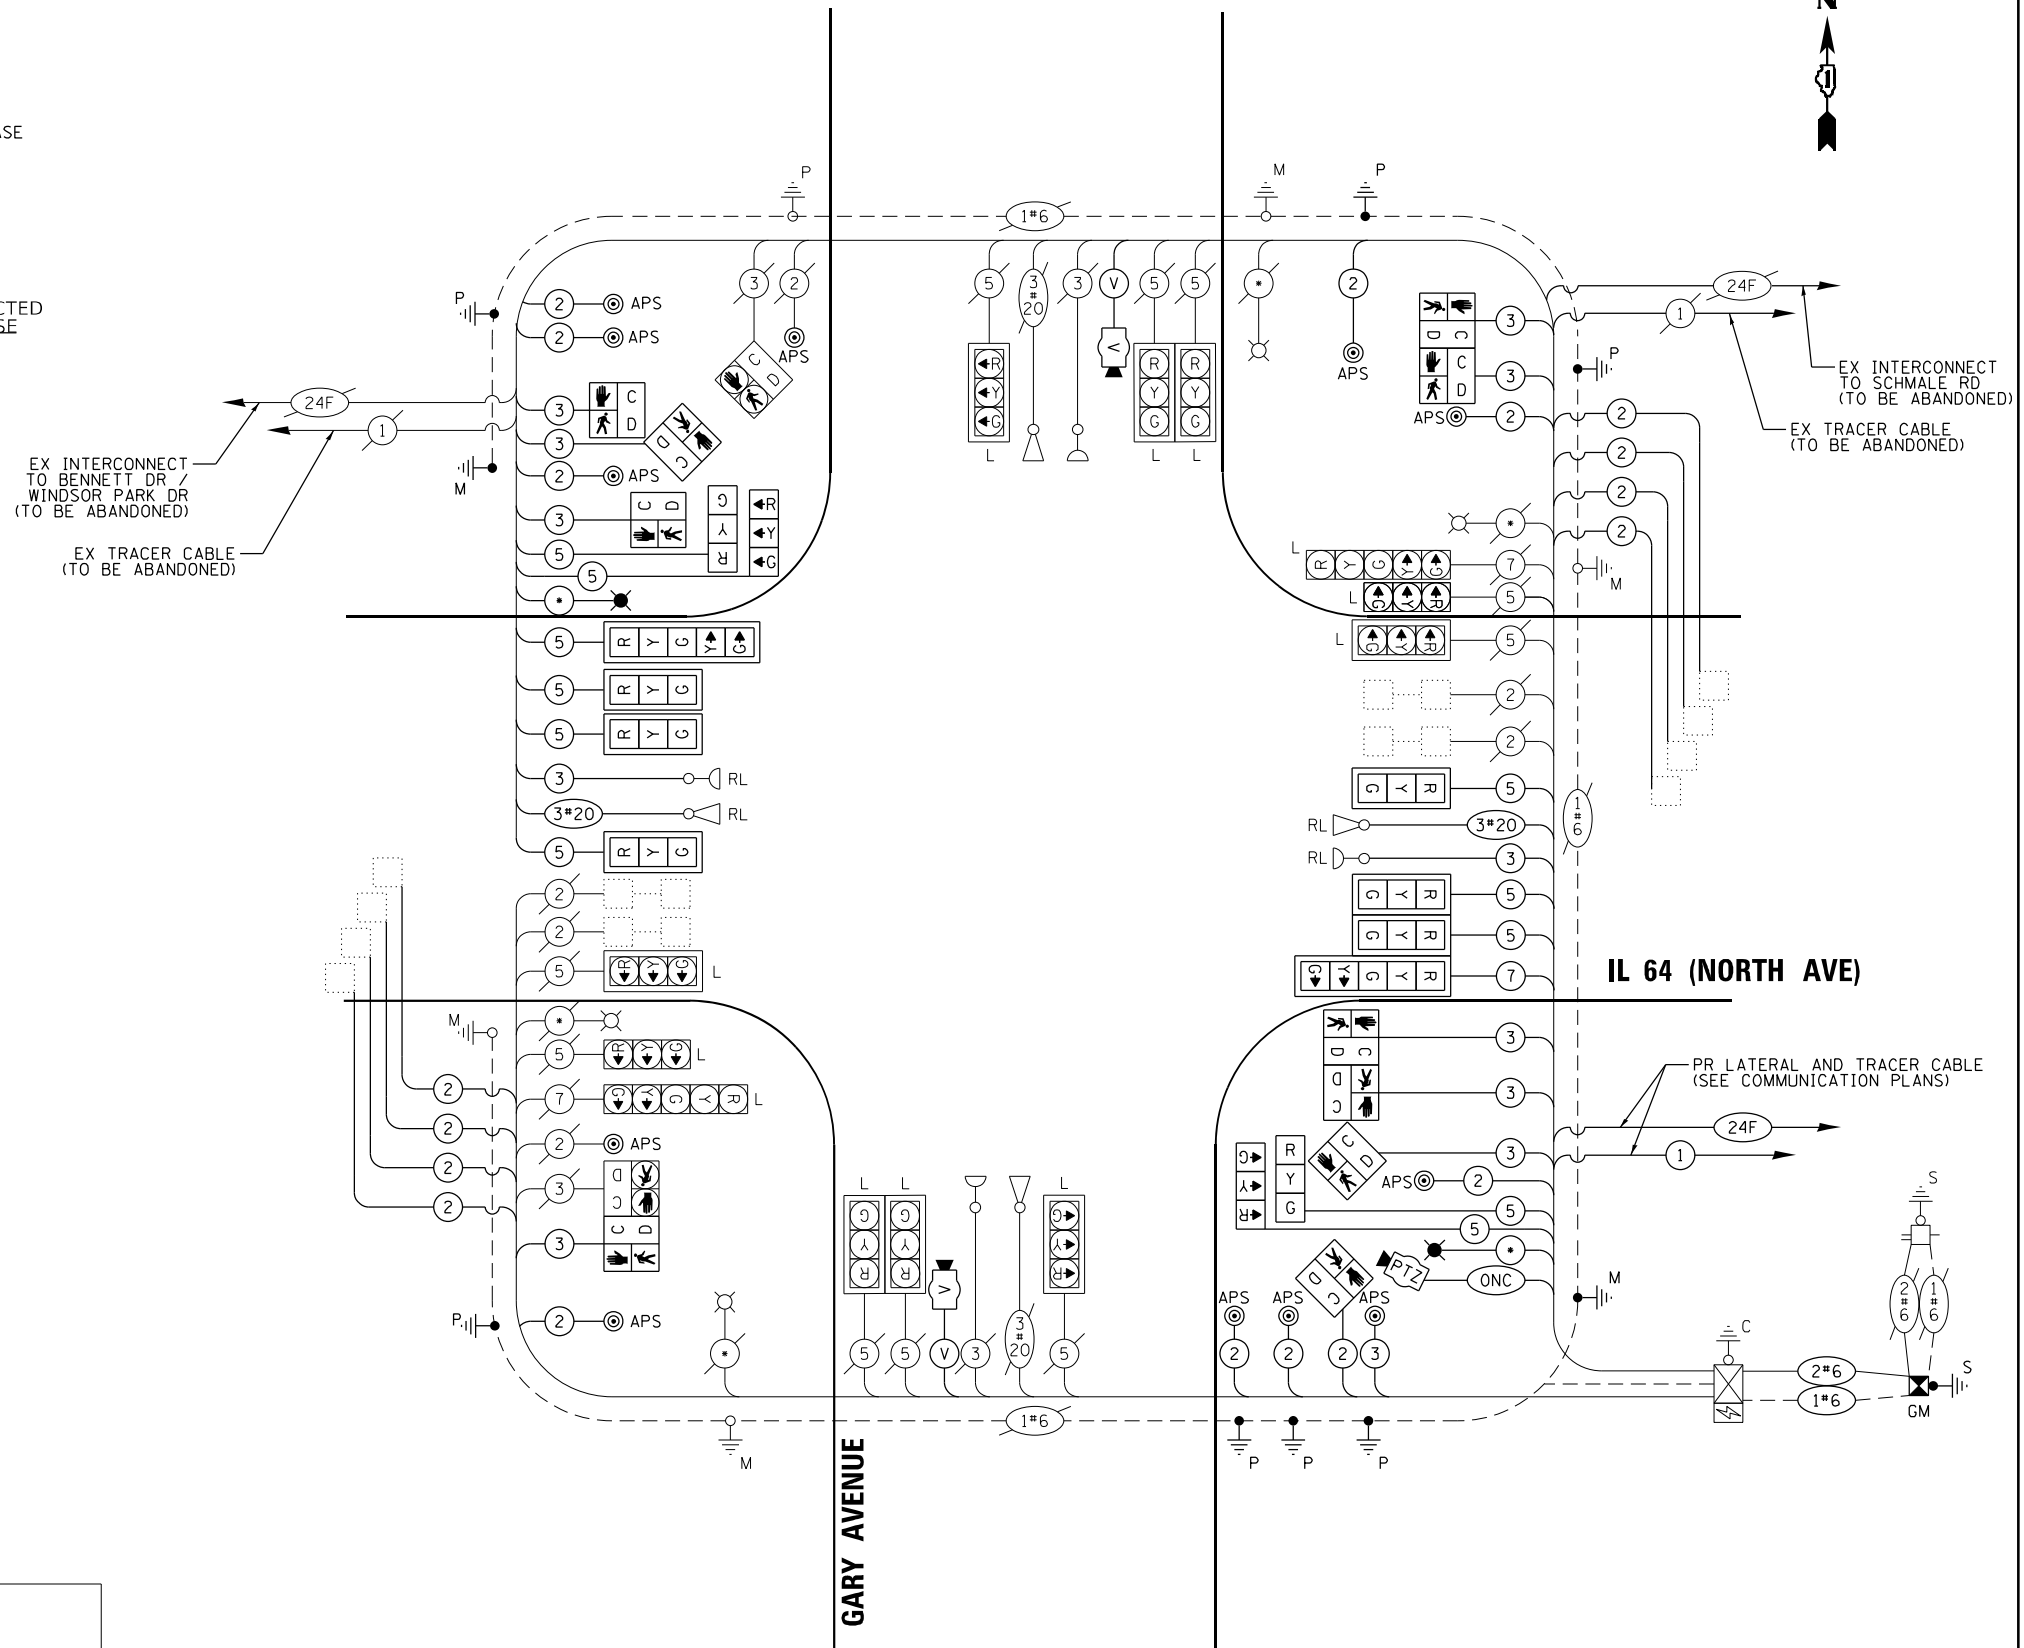

Kimley»Horn

© 2023 KIMLEY-HORN AND ASSOCIATES, INC.
4201 WINTFIELD ROAD, SUITE 603
WARRENVILLE, IL 60555
PHONE: 630-487-5550
WWW.KIMLEY-HORN.COM

USER NAME	=	DESIGNED	-	REVISED	-	
		DRAWN	-	REVISED	-	
PLOT SCALE	=	CHECKED	-	REVISED	-	
PLOT DATE	=	DATE	-	REVISED	-	

STATE OF ILLINOIS
DEPARTMENT OF TRANSPORTATION

**CABLE PLAN, PHASE DESIGNATION DIAGRAM, AND
EMERGENCY VEHICLE PREEMPTION SEQUENCE
IL 64 (NORTH AVE) AND GARY AVE**

SCALE: N.T.S.	SHEET	OF	SHEETS	STA.	TO STA.
---------------	-------	----	--------	------	---------

F.A.P. RTE.	SECTION	COUNTY	TOTAL SHEETS	SHEET NO.
307	2020-263-SUR, SW&TS	DUPAGE	529	176
		CONTRACT NO. 62N33		
		ILLINOIS	FED. AID PROJECT	


TS 6435
IDOT TACTICS
FORMER EAGLE 2E

SIGN PANEL – TYPE 1 OR TYPE 2

ALL DIMENSIONS ARE IN INCHES UNLESS OTHERWISE NOTED



DESIGN SERIES	AREA (SQ FT)	SIGN PANEL TYPE	SHEETING TYPE	QTY. REQUIRED
D	12.5	2	ZZ	2

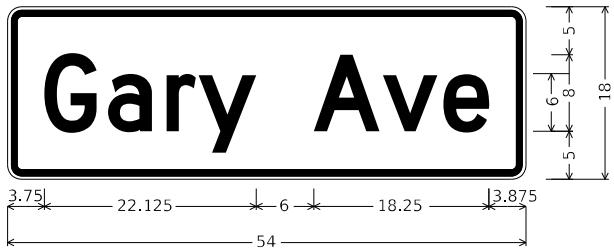

DESIGN SERIES	AREA (SQ FT)	SIGN PANEL TYPE	SHEETING TYPE	QTY. REQUIRED
D	6.75	1	ZZ	2

SCHEDULE OF QUANTITIES

ITEM DESCRIPTION	UNIT	QUANTITY
SIGN PANEL - TYPE 1	SQ FT	66.0
SIGN PANEL - TYPE 2	SQ FT	25
UNDERGROUND CONDUIT, GALVANIZED STEEL, 2" DIA.	FOOT	5
UNDERGROUND CONDUIT, GALVANIZED STEEL, 3" DIA.	FOOT	154
UNDERGROUND CONDUIT, GALVANIZED STEEL, 4" DIA.	FOOT	434
MAINTENANCE OF EXISTING TRAFFIC SIGNAL INSTALLATION	EACH	1
ELECTRIC CABLE IN CONDUIT, SIGNAL NO. 14 2C	FOOT	2460
ELECTRIC CABLE IN CONDUIT, SIGNAL NO. 14 3C	FOOT	3380
ELECTRIC CABLE IN CONDUIT, SIGNAL NO. 14 5C	FOOT	3210
ELECTRIC CABLE IN CONDUIT, SIGNAL NO. 14 7C	FOOT	642
ELECTRIC CABLE IN CONDUIT, LEAD-IN, NO. 14 1 PAIR	FOOT	3304
ELECTRIC CABLE IN CONDUIT, SERVICE, NO. 6 2 C	FOOT	44
ELECTRIC CABLE IN CONDUIT, EQUIPMENT GROUNDING CONDUCTOR, NO. 6 1C	FOOT	632
STEEL COMBINATION MAST ARM ASSEMBLY AND POLE 56 FT.	EACH	1
STEEL COMBINATION MAST ARM ASSEMBLY AND POLE 58 FT.	EACH	1
CONCRETE FOUNDATION, TYPE A	FOOT	4
CONCRETE FOUNDATION, TYPE E 42-INCH DIAMETER	FOOT	42
DRILL EXISTING HANDHOLE	EACH	15
SIGNAL HEAD, LED, 1-FACE, 3-SECTION, MAST-ARM MOUNTED	EACH	6
SIGNAL HEAD, LED, 1-FACE, 3-SECTION, BRACKET MOUNTED	EACH	4
SIGNAL HEAD, LED, 1-FACE, 5-SECTION, BRACKET MOUNTED	EACH	2
PEDESTRIAN SIGNAL HEAD, LED, 1-FACE, BRACKET MOUNTED WITH COUNTDOWN TIMER	EACH	10
TRAFFIC SIGNAL BACKPLATE, LOUVERED, FORMED PLASTIC	EACH	8
INDUCTIVE LOOP DETECTOR	EACH	8
TEMPORARY TRAFFIC SIGNAL INSTALLATION	EACH	1
* RELOCATE EXISTING EMERGENCY VEHICLE PRIORITY SYSTEM, DETECTOR UNIT	EACH	2
REMOVE EXISTING TRAFFIC SIGNAL EQUIPMENT	EACH	1
CLOSED CIRCUIT TELEVISION DOME CAMERA, HD	EACH	1
* EMERGENCY VEHICLE PRIORITY SYSTEM LINE SENSOR CABLE, NO. 20 3/C	FOOT	642
LED LAMP MODULE REPLACEMENT	EACH	40
OUTDOOR RATED NETWORK CABLE	FOOT	182
SERVICE INSTALLATION, GROUND MOUNTED, METERED	EACH	1
LAYER II (DATALINK) SWITCH	EACH	1
TERMINATE FIBER IN CABINET	EACH	12
PEDESTRIAN SIGNAL POST, 10 FT.	EACH	3
PEDESTRIAN SIGNAL POST, 5 FT.	EACH	4
TACTICS LICENSE EXPANSION	EACH	1
RELOCATE EXISTING LUMINAIRE	EACH	2
FULL-ACTUATED CONTROLLER IN EXISTING CABINET	EACH	1
REMOVE AND REPLACE BATTERIES FOR UNINTERRUPTABLE POWER SUPPLY, EXTENDED	EACH	1
FIBER OPTIC INTERCONNECT CENTER, 48 PORT	EACH	1
ACCESSIBLE PEDESTRIAN SIGNALS	EACH	12
CONCRETE FOUNDATION, TYPE A 12-INCH DIAMETER	FOOT	28
LED SIGNAL FACE, LENS COVER	EACH	24
VIDEO VEHICLE DETECTION SYSTEM, SINGLE APPROACH	EACH	2
TEMPORARY TRAFFIC SIGNAL TIMING	EACH	1

* - 100% COST TO THE VILLAGE OF CAROL STREAM

TS 6435
IDOT TACTICS
FORMER EAGLE 2E

MODEL: Default
FILE: Kimley-Horn\pvt-bentley.com\khp-gis\p4-d1\Documents\01 Active Projects\MW\CHS-168959\100 - IL 64\Phase II\2 Design\CAD\Plan_Sheets\Sign\1a\West_Corridor_Signals\ID1081714-rte-36_KHA.dgn

KimleyHorn

© 2021 KIMLEY-HORN AND ASSOCIATES, INC.
4001 HWY 10, SUITE 600
WARREN, IL 60555
PHONE: 815.447.4555
WWW.KIMLEY-HORN.COM

USER NAME =	DESIGNED -	REVISED -
	DRAWN -	REVISED -
PLOT SCALE =	CHECKED -	REVISED -
PLOT DATE =	DATE -	REVISED -

STATE OF ILLINOIS
DEPARTMENT OF TRANSPORTATION

MAST ARM MOUNTED STREET NAME SIGNS AND SCHEDULE OF QUANTITIES IL 64 (NORTH AVE) AND GARY AVE			
SCALE: N.T.S.	SHEET OF SHEETS	STA.	TO STA.

F.A.P. RTE.	SECTION	COUNTY	TOTAL SHEETS	SHEET NO.
307	2020-263-SUR,SW&TS	DUPAGE	529	177
CONTRACT NO. 62N33				
ILLINOIS FED. AID PROJECT				

NOTES

- THE EXISTING TRAFFIC SIGNAL EQUIPMENT SHALL NOT BE REMOVED UNTIL THE PROPOSED TRAFFIC SIGNAL EQUIPMENT IS FULLY OPERATIONAL OR AS DIRECTED BY THE ENGINEER.
- ALL EXISTING TRAFFIC SIGNAL CABLE NO LONGER REQUIRED SHALL BE REMOVED.

RELOCATION NOTES

THE FOLLOWING EXISTING TRAFFIC SIGNAL EQUIPMENT SHALL BE REMOVED BY THE CONTRACTOR, SAFELY STORED AND RELOCATED TO THE PROPOSED MAST ARMS, POSTS, AND TRAFFIC SIGNAL CONTROLLER CABINET.

- | | | |
|---|------|---------------------|
| 4 | EACH | CONFIRMATION BEACON |
| 4 | EACH | LIGHT DETECTOR |

REMOVAL NOTES

THE FOLLOWING ITEMS SHALL BE REMOVED BY THE CONTRACTOR AND SHALL BE DISPOSED OF BY THEM OUTSIDE THE RIGHT-OF-WAY AT THEIR EXPENSE. THE SALVAGE VALUE OF THE REMOVED EQUIPMENT SHALL BE REFLECTED IN CONTRACT BID PRICE.

- | | | |
|----|------|---|
| 20 | EACH | SIGNAL HEAD, 1-FACE, 3-SECTION |
| 4 | EACH | SIGNAL HEAD, 1-FACE, 5-SECTION |
| 1 | EACH | CONTROLLER (M40) |
| 4 | EACH | STREET NAME SIGN PANEL |
| 14 | EACH | TRAFFIC SIGNAL BACKPLATE |
| 2 | EACH | COMBINATION MAST ARM ASSEMBLY AND POLE |
| 2 | EACH | COMBINATION DUAL MAST ARM ASSEMBLY AND POLE |
| 1 | EACH | TRAFFIC SIGNAL POST |

TS 6465
IDOT TACTICS
FORMER EAGLE 2E

KimleyHorn

© 2023 KIMLEY-HORN AND ASSOCIATES, INC.
401 LINDFIELD ROAD, SUITE 600
WARRENVILLE, IL 60555
PHONE: (708) 474-6555
WWW.KHVI-ENGINEERING.COM





USER NAME	=	DESIGNED	-
		DRAWN	-
PLOT SCALE	=	CHECKED	-
PLOT DATE	=	DATE	-

STATE OF ILLINOIS
DEPARTMENT OF TRANSPORTATION

TRAFFIC SIGNAL EQUIPMENT REMOVAL PLAN
IL 64 (NORTH AVE) AND SCHMALE RD

SCALE: 1" = 20' SHEET OF SHEETS STA. TO STA.

F.A.P. RTE.	SECTION	COUNTY	TOTAL SHEETS	SHEET NO.
307	2020-263-SUR.SW&TS	DUPAGE	529	178
CONTRACT NO. 62N33				
ILLINOIS FED. AID PROJECT				

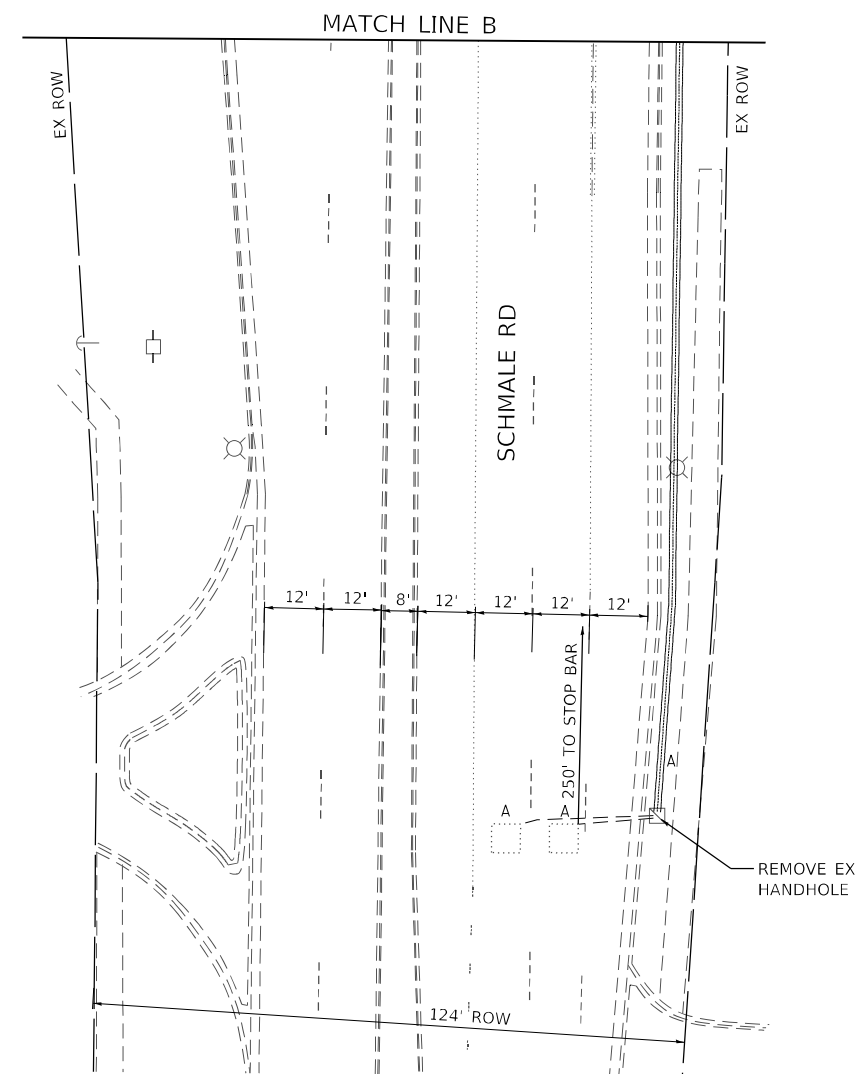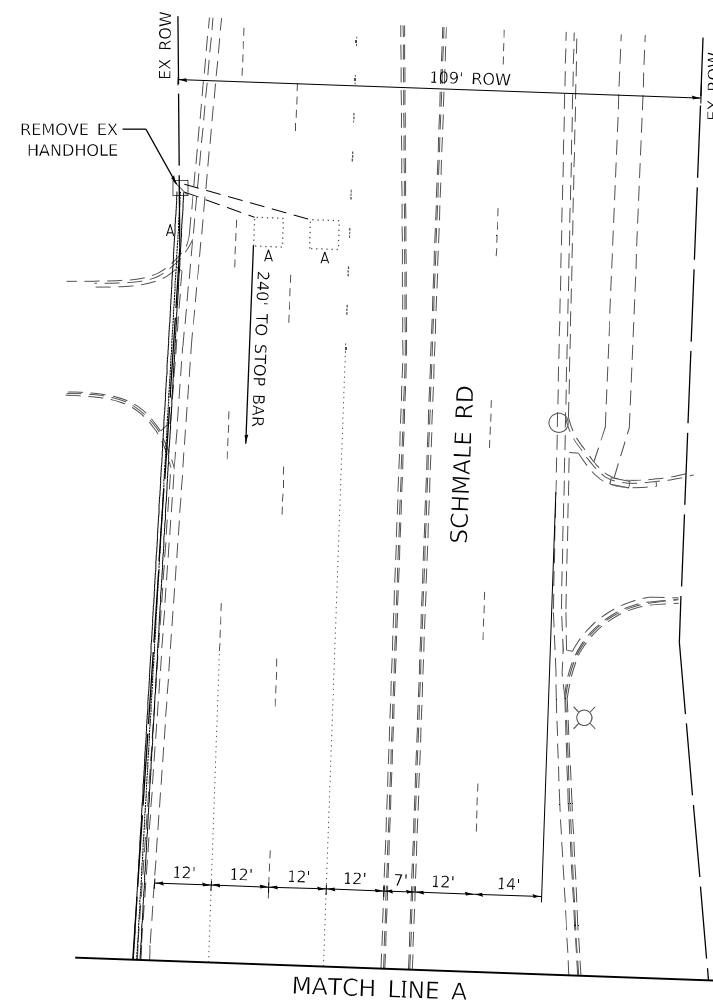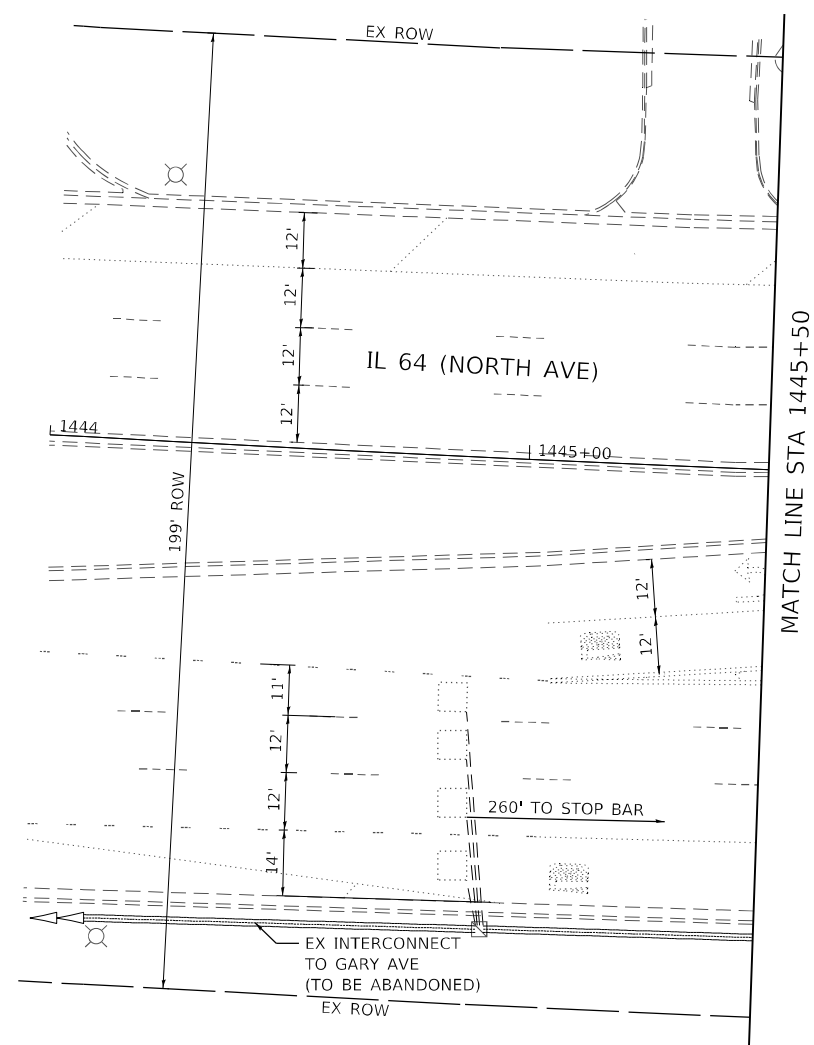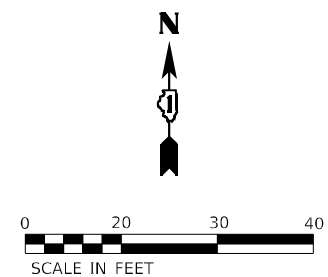

TS 6465
IDOT TACTICS
FORMER EAGLE 2E

Kimley»Horn
© 2023 KIMLEY-HORN AND ASSOCIATES, INC.
4201 WILFIELD ROAD, SUITE 603
WARRENVILLE, IL 60555
PHONE: 630-487-8550
WWW.KIMLEY-HORN.COM

USER NAME =	DESIGNED -	REVISED -
	DRAWN -	REVISED -
PLOT SCALE =	CHECKED -	REVISED -
PLOT DATE =	DATE -	REVISED -


**STATE OF ILLINOIS
DEPARTMENT OF TRANSPORTATION**

**TRAFFIC SIGNAL EQUIPMENT REMOVAL PLAN
IL 64 (NORTH AVE) AND SCHMALE RD**

SCALE: 1" = 20'	SHEET	OF	SHEETS	STA.	TO STA.
-----------------	-------	----	--------	------	---------

F.A.P. RTE.	SECTION	COUNTY	TOTAL SHEETS	SHEET NO.
307	2020-263-SUR, SW&TS	DUPAGE	529	179
		CONTRACT NO. 62N33		
		ILLINOIS FED. AID PROJECT		

1. ALL PROPOSED TRAFFIC SIGNAL CABLE SHALL BE ROUTED THROUGH THE PROPOSED CONDUIT.
2. A SEPARATE LEAD-IN CABLE SHALL BE INSTALLED FOR THE DETECTOR LOOPS ON IL 64 (NORTH AVE).
3. THERE SHALL BE A MINIMUM OF 4' SIDEWALK CLEARANCE IN FRONT/BEHIND OF THE TRAFFIC SIGNAL FOUNDATIONS TO BE ADA COMPLIANT.
4. THE SIDEWALK CURBS ON ALL QUADRANTS SHALL BE CUT SO THAT THE POST AND MAST ARM FOUNDATIONS ARE FLUSH WITH THE EDGE OF THE SIDEWALK.
5. ALL PUSH BUTTONS SHALL BE APS.
6. THIS LOCATION HAS BEEN DESIGNED TO BE ADA COMPLIANT. ANY DEVIATION FROM THIS PLAN FOR THE POSTS THAT HAVE PEDESTRIAN EQUIPMENT WILL HAVE TO BE APPROVED BY THE ENGINEER TO ENSURE ADA COMPLIANCE.
7. CONTRACTOR SHALL VERIFY THAT THE PLACEMENT OF THE PROPOSED SIGNAL EQUIPMENT ADJACENT TO EXISTING RAMPS MEET ADA REQUIREMENTS. THE ENGINEER SHALL APPROVE THE PROPOSED LOCATIONS OF THE SIGNAL EQUIPMENT BEFORE INSTALLATION.

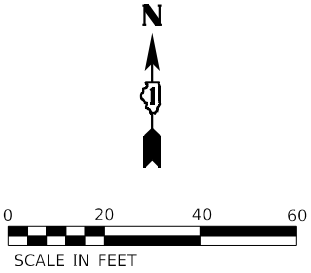

R10-5
30" X 36"
(8 REQUIRED)

© 2023 KIMLEY-HORN AND ASSOCIATES, INC.
4201 WHITFIELD ROAD, SUITE 603
WARRENVILLE, IL 60555
PHONE: 630-487-5550
WWW.KIMLEY-HORN.COM



USER NAME	=
PLOT SCALE	=
PLOT DATE	=

DESIGNED	-
DRAWN	-
CHECKED	-
DATE	-

REVISED	-
REVISED	-
REVISED	-
REVISED	-

SCALE: 1" = 20'	SHEET	OF	SHEETS	STA.	TO STA.
-----------------	-------	----	--------	------	---------

F.A.P. RTE.	SECTION	COUNTY	TOTAL SHEETS	SHEET NO.
307	2020-263-SUR,SW&TS	DUPAGE	529	180
		CONTRACT NO. 62N33		
ILLINOIS		FED. AID PROJECT		

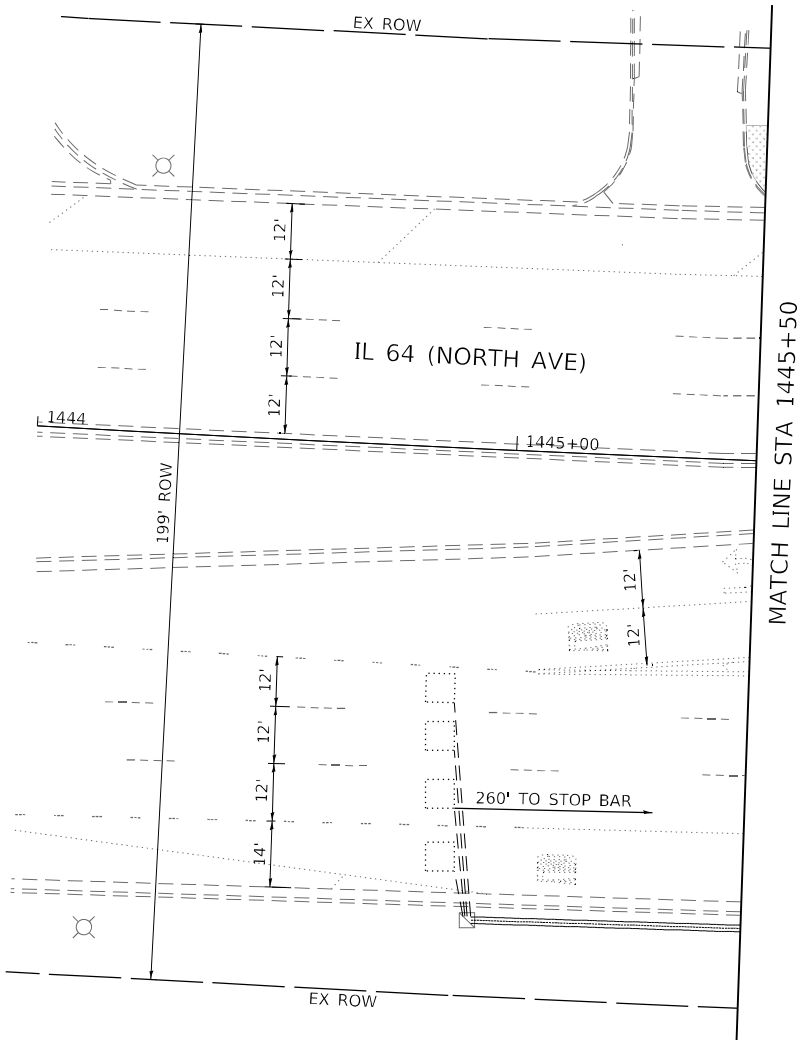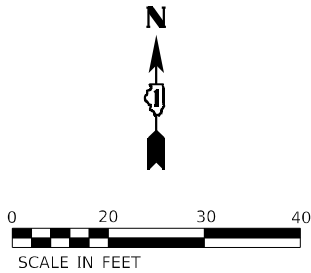

MODEL: Default
FILE: h:\mhc\projects\pva\bartley.com\h-pva-d1\Documents\01 Active Projects\MW\CHS-168950\00 - IL 64\Phase II\2 Design\CAD\Plan_Sheets\Signal\West Corridor_Signal\010817-1445+50_KIM.dgn

Kimley»Horn

© 2023 KIMLEY-HORN AND ASSOCIATES, INC.
4001 WHITE OAK ROAD, SUITE 600
WARREN, ILL. 60555
PHONE: 815.477.4555
WWW.KIMLEY-HORN.COM

USER NAME	=	DESIGNED	-
		DRAWN	-
PLOT SCALE	=	CHECKED	-
PLOT DATE	=	DATE	-
		REVISED	-
		REVISED	-
		REVISED	-
		REVISED	-

STATE OF ILLINOIS
DEPARTMENT OF TRANSPORTATION


TRAFFIC SIGNAL MODERNIZATION PLAN
IL 64 (NORTH AVE) AND SCHMALE RD

SCALE: 1" = 20' SHEET OF SHEETS STA. TO STA.


F.A.P. RTE.	SECTION	COUNTY	TOTAL SHEETS	SHEET NO.
307	2020-263-SUR,SW&TS	DUPAGE	529	181
CONTRACT NO. 62N33				
		ILLINOIS	FED. AID PROJECT	

TS 6465
IDOT TACTICS
FORMER EAGLE 2E

EXISTING CONTROLLER SEQUENCE

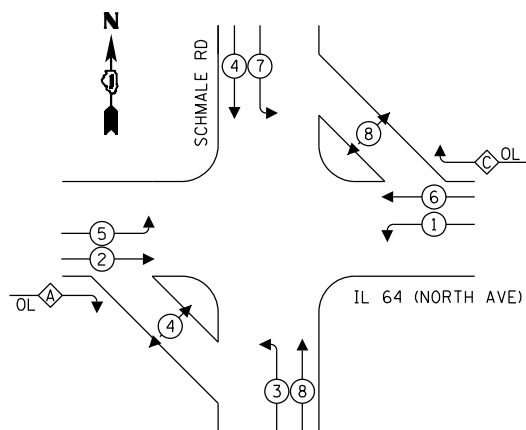


PROPOSED
CONTROLLER SEQUENCE

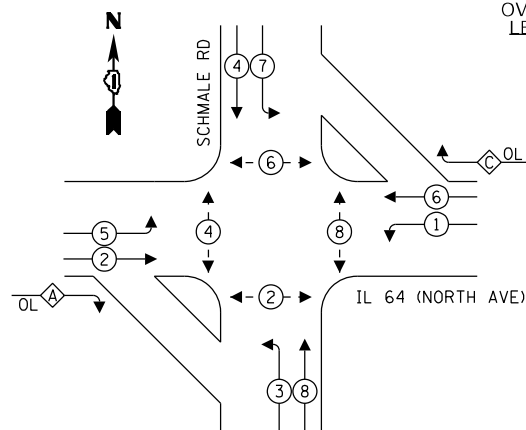

OVERLAP LETTER		PERMISSIVE PHASE		PROTECTED PHASE
A	=	2	+	3
C	=	6	+	7

EXISTING AND PROPOSED EMERGENCY VEHICLE PREEMPTION SEQUENCE

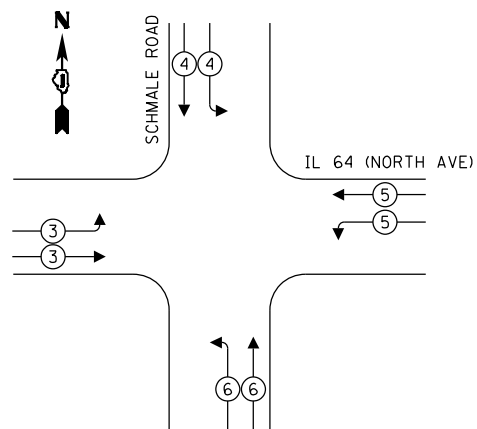

TRAFFIC SIGNAL ELECTRICAL SERVICE REQUIREMENTS

TYPE	QUANTITY	UNIT WATTAGE	TOTAL WATTAGE
SIGNAL HEAD 1 OR 3-SECTION	19	11	209
4-SECTION	-	14	-
5-SECTION	4	13	52
PROGRAMMABLE 3-SECTION	-	22	-
4-SECTION	-	32	-
5-SECTION	-	28	-
PEDESTRIAN SIGNAL	12	15	180
CONTROLLER	1	150	150
MASTER CONTROLLER	-	100	-
UPS	1	25	25
DETECTION RADAR OR VIDEO	2	20	40
BLANK-OUT SIGN	-	25	-
NETWORK SWITCH II OR III	1	35	35
CELLULAR MODEM	-	15	-
PTZ	1	75	75
TOTAL UPS SIZING			691
UPS CHARGING	1	225	225
BATTERY HEATER MAT	1	180	180
CABINET HEATER	1	200	200
FLASHER	-	15	-
LED STREET NAME SIGN	-	120	-
LUMINAIRE	4	240	960
TOTAL SERVICE WIRE SIZING			2256

ENERGY COSTS TO:
ILLINOIS DEPARTMENT OF TRANSPORTATION
201 W CENTER CT
SCHAUMBURG, IL 60196

ENERGY SUPPLY: COMPANY: COMED
PHONE: (866) 639-3532
ACCOUNT NUMBER: 00940-45191

LEGEND:


-  PROTECTED PHASE
 PROTECTED/PERMITTED PHASE
 PEDESTRIAN PHASE
 OVERLAP

LEGEND:

* = ROADWAY LIGHTING CABLE

CABLE PLAN

(NOT TO SCALE)

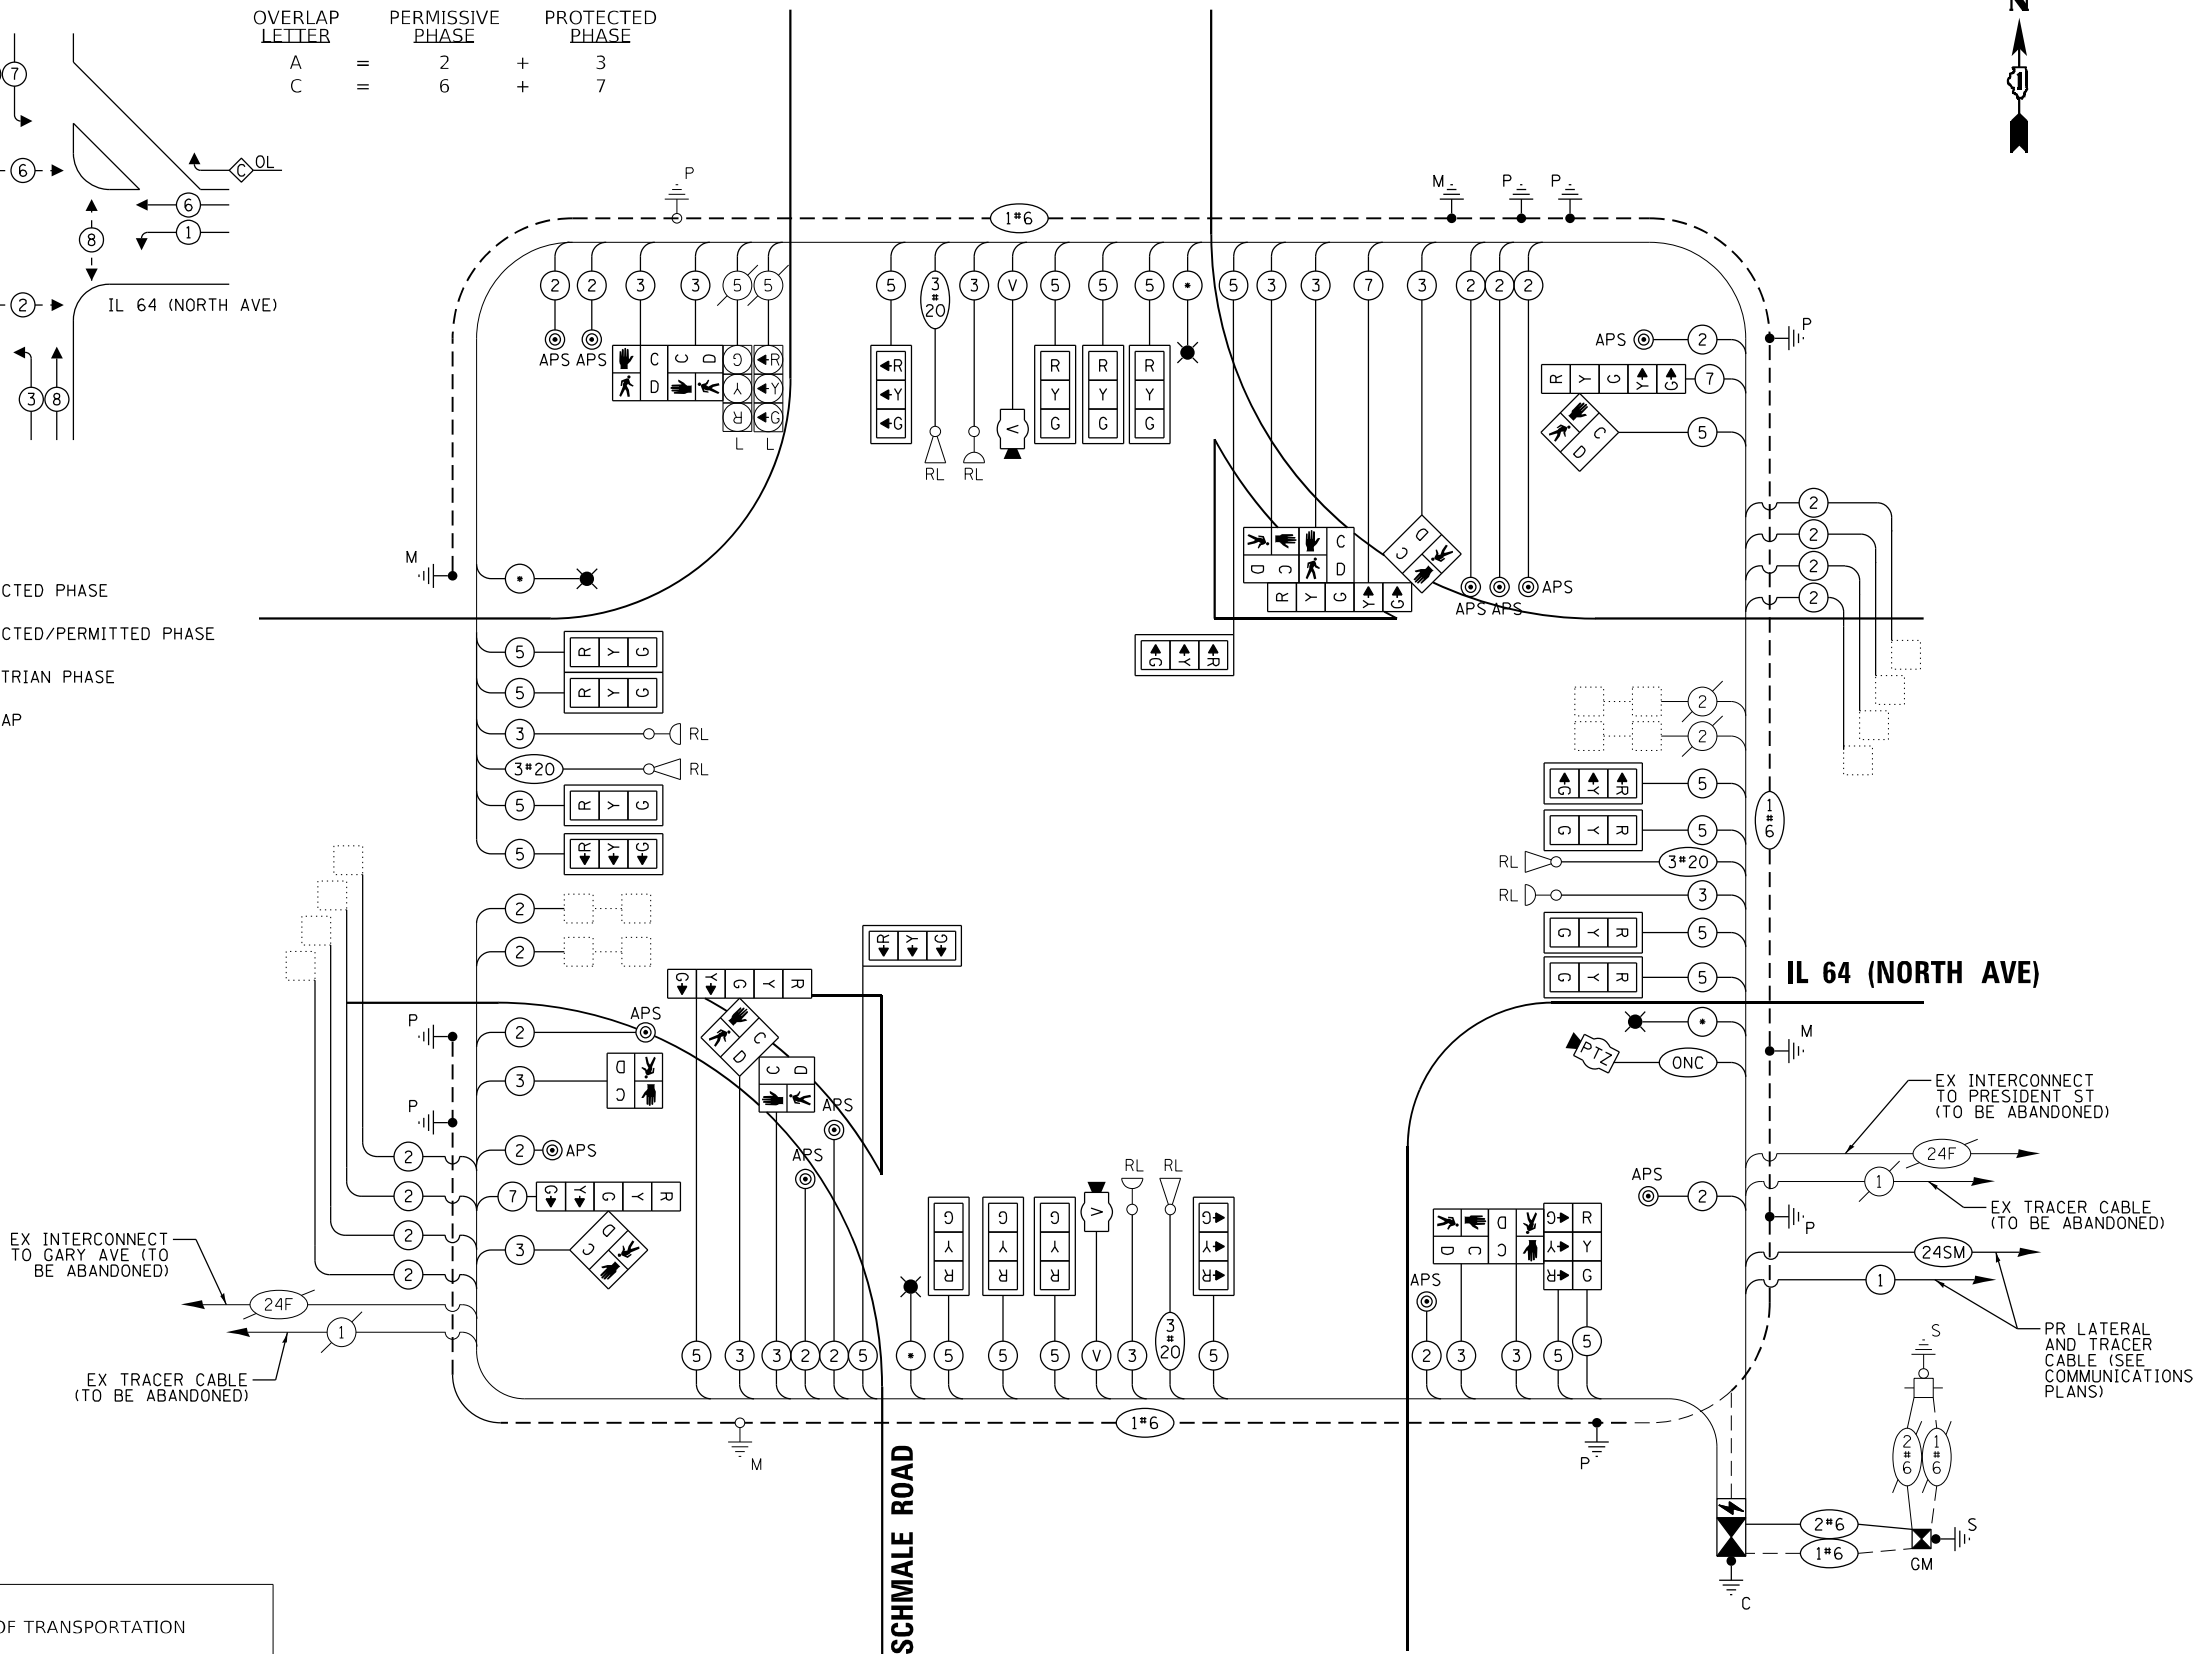

**TS 6465
IDOT TACTICS
FORMER EAGLE 2E**

Kimley»Horn

© 2023 KIMLEY-HORN AND ASSOCIATES, INC.
4201 WINFIELD ROAD, SUITE 603
WARREN, IL 60555
PHONE: 830-487-6550
WWW.KIMLEY-HORN.COM

USER NAME	=
PLOT SCALE	=
PLOT DATE	=

DESIGNED -
DRAWN -
CHECKED -
DATE -

REVISED	-
REVISED	-
REVISED	-
REVISED	-

STATE OF ILLINOIS
DEPARTMENT OF TRANSPORTATION

**CABLE PLAN, PHASE DESIGNATION DIAGRAM, AND
EMERGENCY VEHICLE PREEMPTION SEQUENCE
IL 64 (NORTH AVE) AND SCHMALE RD**

SCALE: N.T.S.	SHEET	OF	SHEETS	STA.	TO STA.
---------------	-------	----	--------	------	---------

F.A.P. RTE.	SECTION	COUNTY	TOTAL SHEETS	SHEET NO.
307	2020-263-SUR,SW&TS	DUPAGE	529	182
		CONTRACT NO. 62N33		
ILLINOIS		FED. AID PROJECT		

ALL DIMENSIONS ARE IN INCHES UNLESS OTHERWISE NOTED




DESIGN SERIES	AREA (SQ. FT)	SIGN PANEL TYPE	SHEETING TYPE	QTY. REQUIRED
D	12.5	2	ZZ	2

ITEM DESCRIPTION	UNIT	QUANTITY
SIGN PANEL - TYPE 1	SQ FT	76.5
SIGN PANEL - TYPE 2	SQ FT	25
UNDERGROUND CONDUIT, GALVANIZED STEEL, 2" DIA.	FOOT	5
UNDERGROUND CONDUIT, GALVANIZED STEEL, 3" DIA.	FOOT	138
UNDERGROUND CONDUIT, GALVANIZED STEEL, 4" DIA.	FOOT	353
MAINTENANCE OF EXISTING TRAFFIC SIGNAL INSTALLATION	EACH	1
ELECTRIC CABLE IN CONDUIT, SIGNAL NO. 14 2C	FOOT	3001
ELECTRIC CABLE IN CONDUIT, SIGNAL NO. 14 3C	FOOT	4528
ELECTRIC CABLE IN CONDUIT, SIGNAL NO. 14 5C	FOOT	6158
ELECTRIC CABLE IN CONDUIT, SIGNAL NO. 14 7C	FOOT	902
ELECTRIC CABLE IN CONDUIT, LEAD-IN, NO. 14 1 PAIR	FOOT	1684
ELECTRIC CABLE IN CONDUIT, SERVICE, NO. 6 2 C	FOOT	38
ELECTRIC CABLE IN CONDUIT, EQUIPMENT GROUNDING CONDUCTOR, NO. 6 1C	FOOT	529
TRAFFIC SIGNAL POST, GALVANIZED STEEL 16 FT.	EACH	3
STEEL COMBINATION MAST ARM ASSEMBLY AND POLE 75 FT.	EACH	2
STEEL COMBINATION MAST ARM ASSEMBLY AND POLE WITH DUAL MAST ARMS, 28 FT. AND 50 FT.	EACH	2
CONCRETE FOUNDATION, TYPE A	FOOT	16
CONCRETE FOUNDATION, TYPE E 36-INCH DIAMETER	FOOT	32
CONCRETE FOUNDATION, TYPE E 42-INCH DIAMETER	FOOT	50
DRILL EXISTING HANDHOLE	EACH	13
SIGNAL HEAD, LED, 1-FACE, 3-SECTION, MAST-ARM MOUNTED	EACH	14
SIGNAL HEAD, LED, 1-FACE, 3-SECTION, BRACKET MOUNTED	EACH	2
SIGNAL HEAD, LED, 1-FACE, 5-SECTION, BRACKET MOUNTED	EACH	4
PEDESTRIAN SIGNAL HEAD, LED, 1-FACE, BRACKET MOUNTED WITH COUNTDOWN TIMER	EACH	12
TRAFFIC SIGNAL BACKPLATE, LOUVERED, FORMED PLASTIC	EACH	14
INDUCTIVE LOOP DETECTOR	EACH	10
RELOCATE EXISTING EMERGENCY VEHICLE PRIORITY SYSTEM, DETECTOR UNIT	EACH	4
REMOVE EXISTING TRAFFIC SIGNAL EQUIPMENT	EACH	1
REMOVE EXISTING HANDHOLE	EACH	2
REMOVE EXISTING CONCRETE FOUNDATION	EACH	5
CLOSED CIRCUIT TELEVISION DOME CAMERA, HD	EACH	1
EMERGENCY VEHICLE PRIORITY SYSTEM LINE SENSOR CABLE, NO. 20 3/C	FOOT	1332
OUTDOOR RATED NETWORK CABLE	FOOT	135
SERVICE INSTALLATION, GROUND MOUNTED, METERED	EACH	1
REMOTE CONTROLLED VIDEO SYSTEM	EACH	1
LAYER II (DATALINK) SWITCH	EACH	1
TERMINATE FIBER IN CABINET	EACH	12
PEDESTRIAN SIGNAL POST, 10 FT.	EACH	2
PEDESTRIAN SIGNAL POST, 5 FT.	EACH	1
TACTICS LICENSE EXPANSION	EACH	1
FULL-ACTUATED CONTROLLER IN EXISTING CABINET	EACH	1
REMOVE AND REPLACE BATTERIES FOR UNINTERRUPTABLE POWER SUPPLY, EXTENDED	EACH	1
FIBER OPTIC INTERCONNECT CENTER, 48 PORT	EACH	1
ACCESSIBLE PEDESTRIAN SIGNALS	EACH	12
CONCRETE FOUNDATION, TYPE A 12-INCH DIAMETER	FOOT	12
LED SIGNAL FACE, LENS COVER	EACH	25
VIDEO VEHICLE DETECTION SYSTEM, SINGLE APPROACH	EACH	2
CAMERA MOUNTING ASSEMBLY	EACH	1

**TS 6465
IDOT TACTICS
FORMER EAGLE 2E**

NOTES

1. THE EXISTING TRAFFIC SIGNAL EQUIPMENT SHALL NOT BE REMOVED UNTIL THE PROPOSED TRAFFIC SIGNAL EQUIPMENT IS FULLY OPERATIONAL OR AS DIRECTED BY THE ENGINEER.
2. ALL EXISTING TRAFFIC SIGNAL CABLE NO LONGER REQUIRED SHALL BE REMOVED.
3. THE REMOVAL OF THE EXISTING MASTER CONTROLLER SHALL INCLUDE DISCONNECTING THE EXISTING TELEPHONE SERVICE.

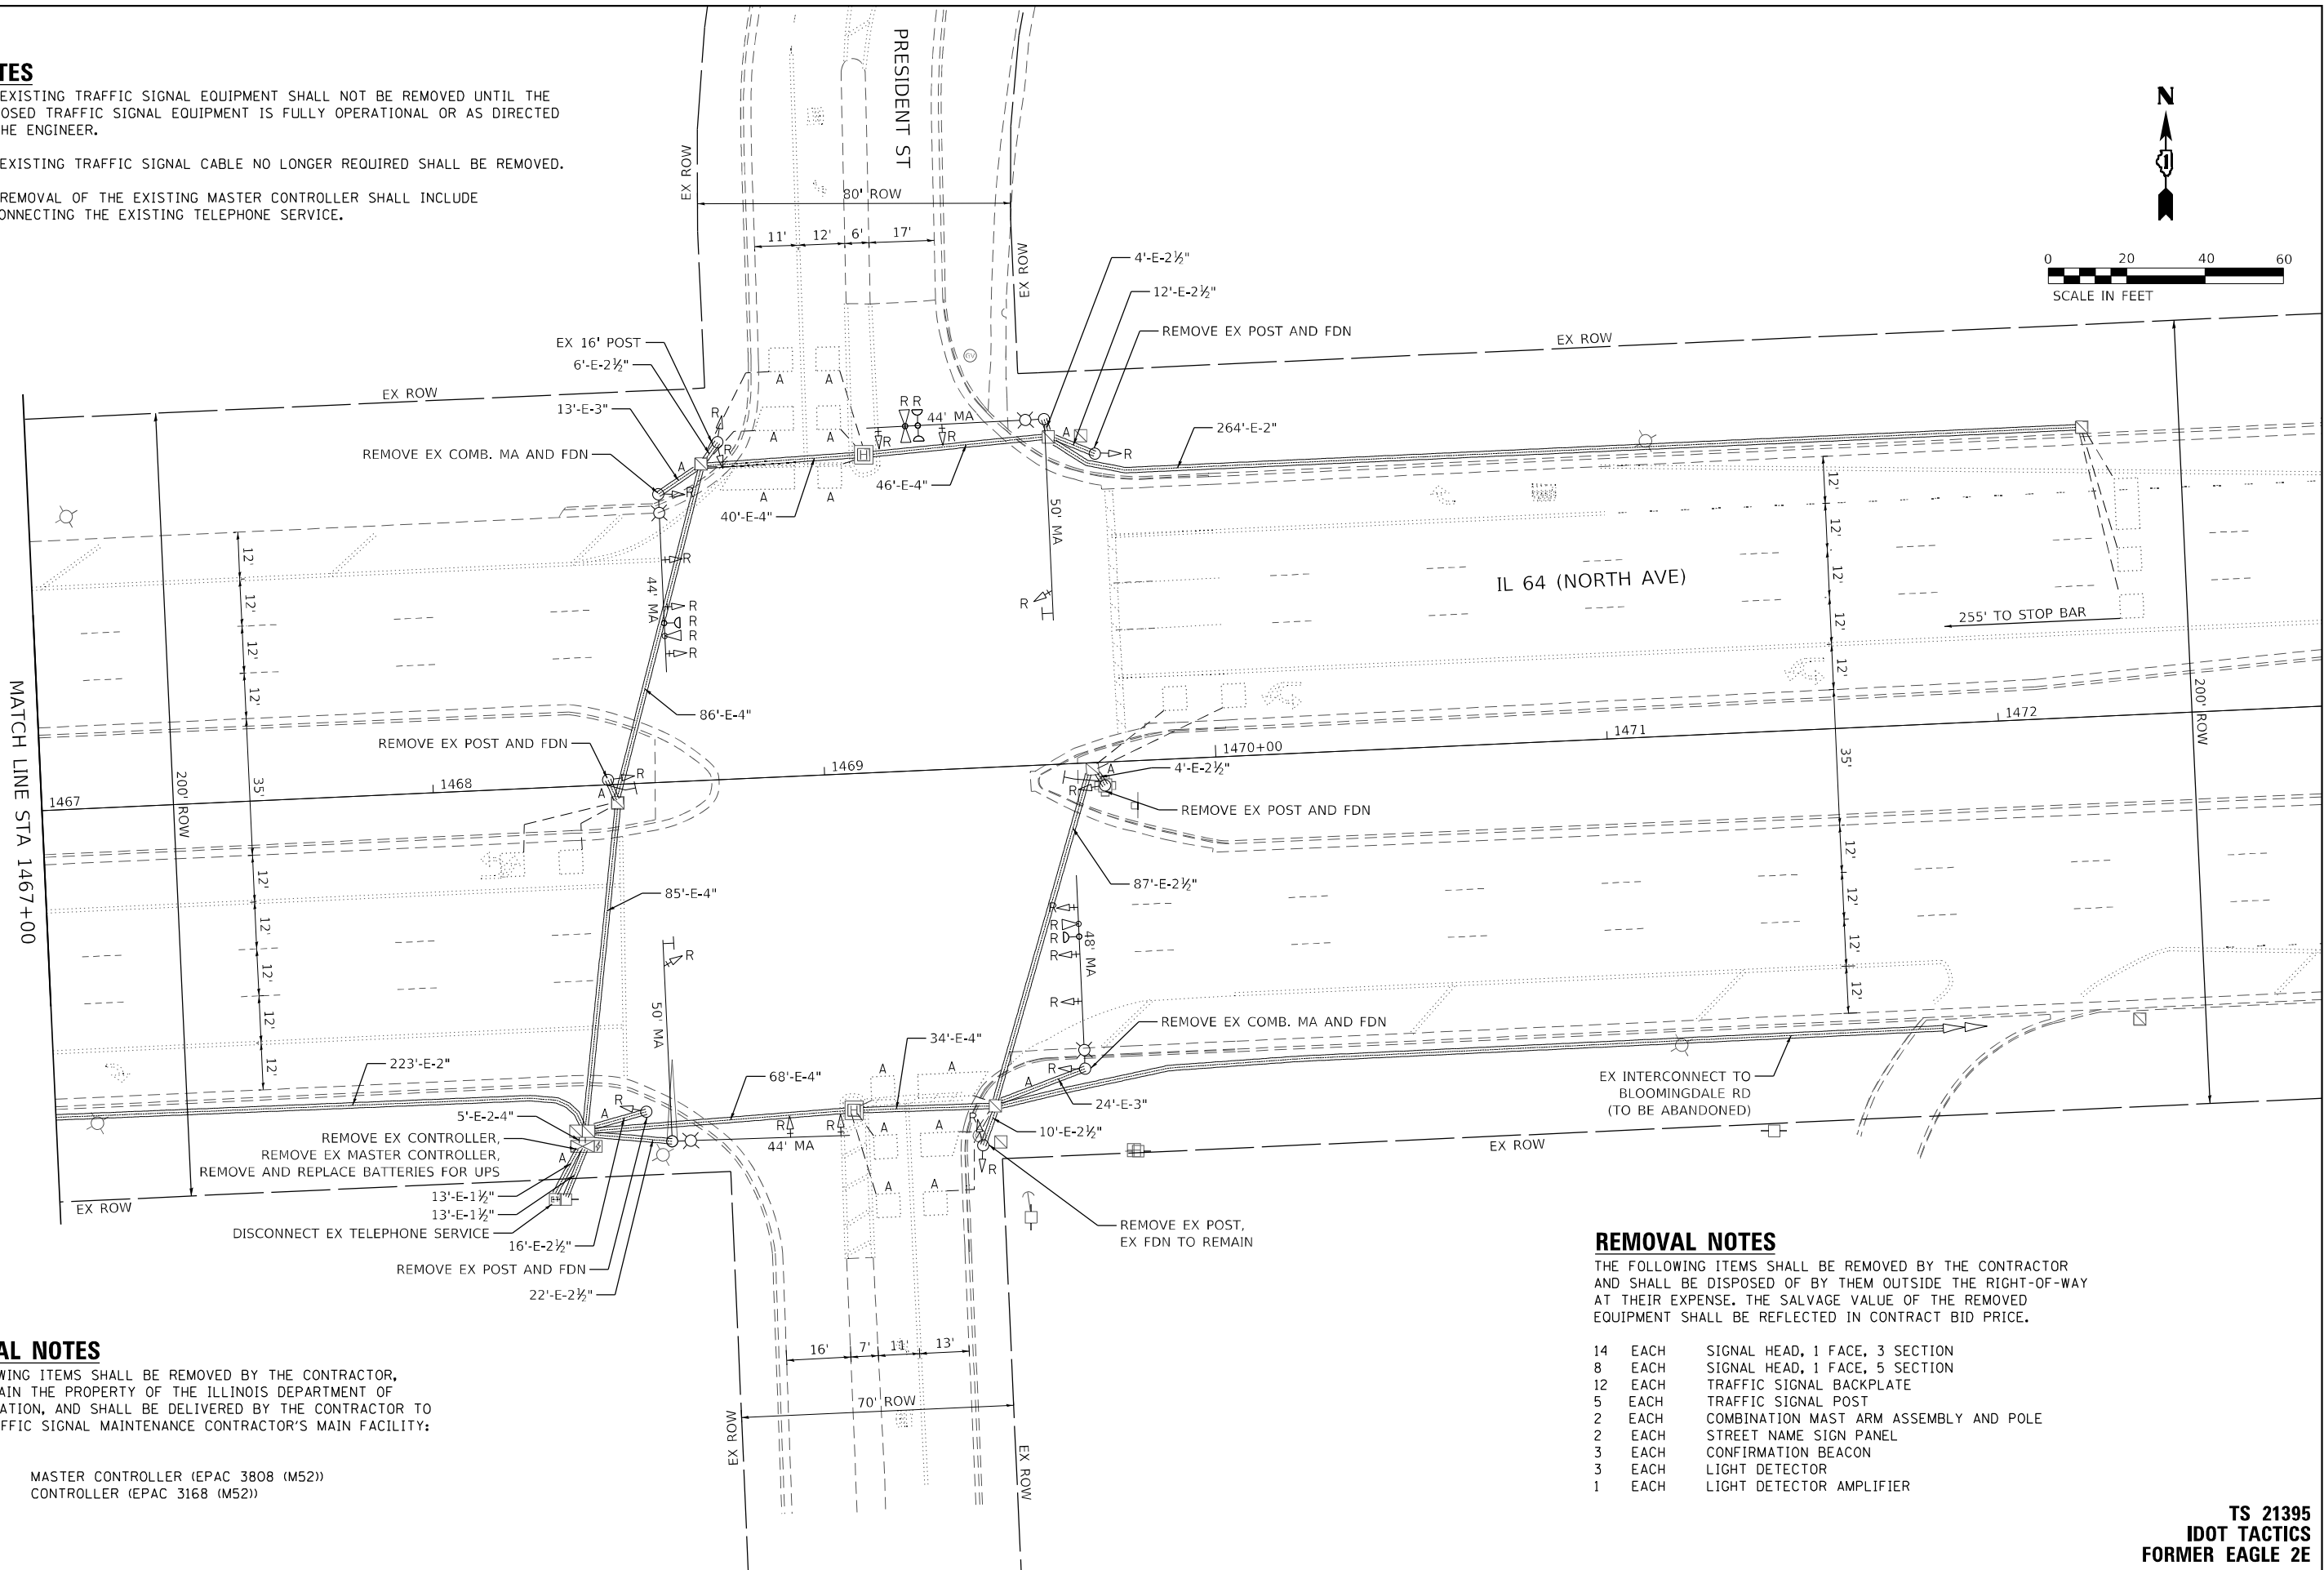

REMOVAL NOTES

THE FOLLOWING ITEMS SHALL BE REMOVED BY THE CONTRACTOR, SHALL REMAIN THE PROPERTY OF THE ILLINOIS DEPARTMENT OF TRANSPORTATION, AND SHALL BE DELIVERED BY THE CONTRACTOR TO IDOT'S TRAFFIC SIGNAL MAINTENANCE CONTRACTOR'S MAIN FACILITY:

- | | | |
|---|------|-------------------------------------|
| 1 | EACH | MASTER CONTROLLER (EPAC 3808 (M52)) |
| 1 | EACH | CONTROLLER (EPAC 3168 (M52)) |

REMOVAL NOTES

THE FOLLOWING ITEMS SHALL BE REMOVED BY THE CONTRACTOR AND SHALL BE DISPOSED OF BY THEM OUTSIDE THE RIGHT-OF-WAY AT THEIR EXPENSE. THE SALVAGE VALUE OF THE REMOVED EQUIPMENT SHALL BE REFLECTED IN CONTRACT BID PRICE.

- | | | |
|----|------|--|
| 14 | EACH | SIGNAL HEAD, 1 FACE, 3 SECTION |
| 8 | EACH | SIGNAL HEAD, 1 FACE, 5 SECTION |
| 12 | EACH | TRAFFIC SIGNAL BACKPLATE |
| 5 | EACH | TRAFFIC SIGNAL POST |
| 2 | EACH | COMBINATION MAST ARM ASSEMBLY AND POLE |
| 2 | EACH | STREET NAME SIGN PANEL |
| 3 | EACH | CONFIRMATION BEACON |
| 3 | EACH | LIGHT DETECTOR |
| 1 | EACH | LIGHT DETECTOR AMPLIFIER |

MODEL: Default
FILE: \\hwy-ty-bentley.com\hwy-bentley\cadd\p4\11\documents\01 Active Projects\MW\CL-S-68095\000 - IL 64\Phase 0\2 Design\CAD\Plan_Sheets\Signal\West Corridor_Signals\01081714-IL-64-33_KW.dgn



© 2023 KIMLEY-HORN AND ASSOCIATES, INC.
4001 HWY 10 ROAD, SUITE 600
WARREN, IL 60555
PHONE: (847) 455-4555
WWW.KH-IL.COM

USER NAME	=	DESIGNED	-
		DRAWN	-
PLOT SCALE	=	CHECKED	-
PLOT DATE	=	DATE	-

REVISED	-
REVISED	-
REVISED	-
REVISED	-



STATE OF ILLINOIS
DEPARTMENT OF TRANSPORTATION

TRAFFIC SIGNAL EQUIPMENT REMOVAL PLAN
IL 64 (NORTH AVE) AND PRESIDENT ST

SCALE: 1" = 20' SHEET OF SHEETS STA. TO STA.

F.A.P. RTE.	SECTION	COUNTY	TOTAL SHEETS	SHEET NO.
307	2020-263-SUR,SW&TS	DUPAGE	529	184
CONTRACT NO. 62N33				
ILLINOIS FED. AID PROJECT				

TS 21395
IDOT TACTICS
FORMER EAGLE 2E

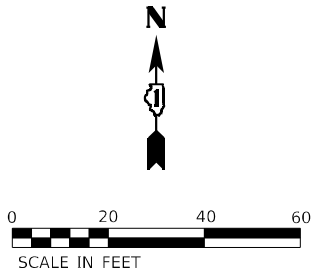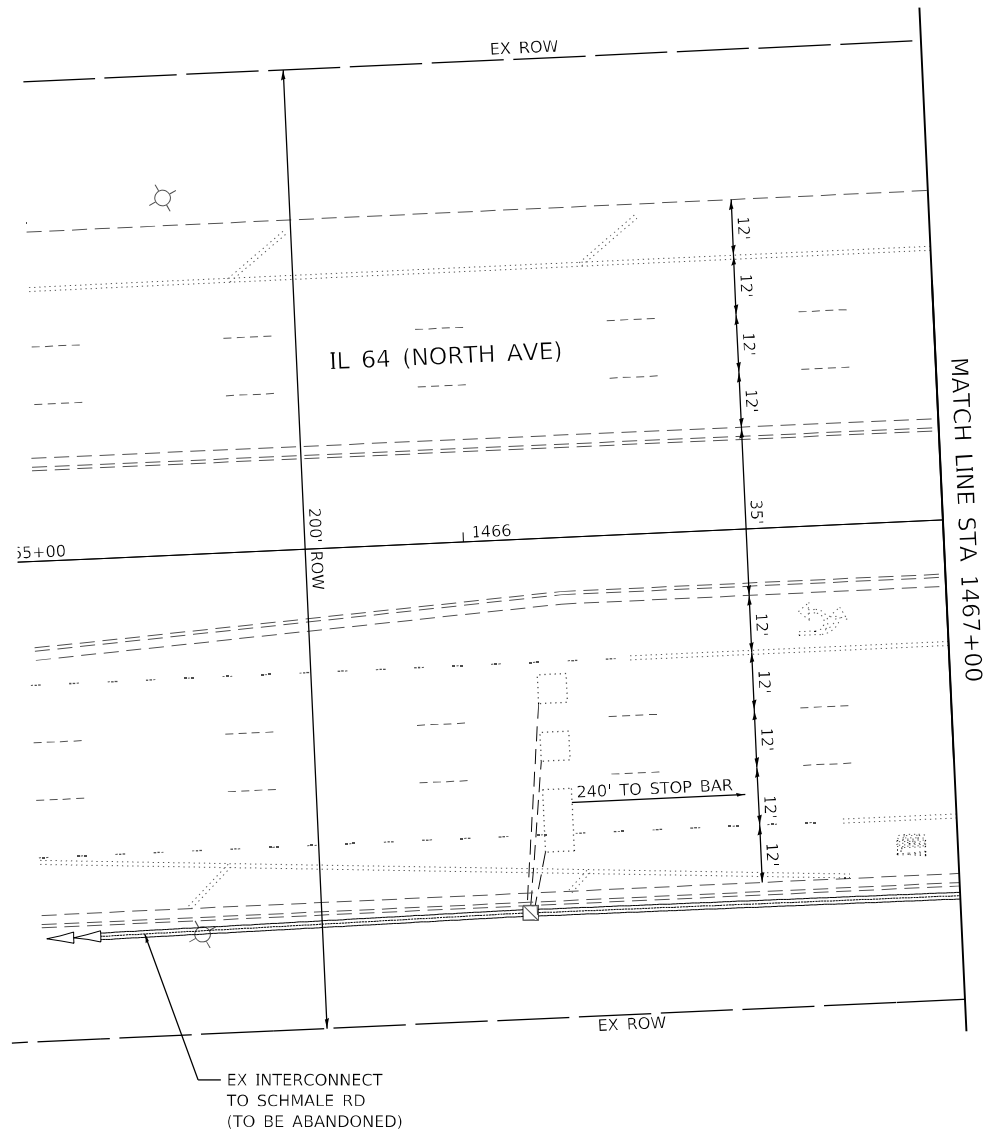

TS 21395
IDOT TACTICS
FORMER EAGLE 2E

MODEL: Default
FILE NAME: p:\sub-pw\bartley.com\k-h-pw-d\Documents\01 Active Projects\IMW-CL-S-16895\000 - IL 64\Phase 1\12 Design\CAD\Plan Streets\Signal\West Corridor Signal\ID 1081714-IL-64-K4A.dgn





USER NAME =	DESIGNED -	REVISED -
	DRAWN -	REVISED -
PLOT SCALE =	CHECKED -	REVISED -
PLOT DATE =	DATE -	REVISED -

STATE OF ILLINOIS
DEPARTMENT OF TRANSPORTATION

TRAFFIC SIGNAL EQUIPMENT REMOVAL PLAN			
IL 64 (NORTH AVE) AND PRESIDENT ST			
SCALE: 1" = 20'	SHEET	OF	SHEETS
STA.		TO STA.	

F.A.P. RTE.	SECTION	COUNTY	TOTAL SHEETS	SHEET NO.
307	2020-263-SUR,SW&TS	DUPAGE	529	185
CONTRACT NO. 62N33				
ILLINOIS		FED. AID PROJECT		

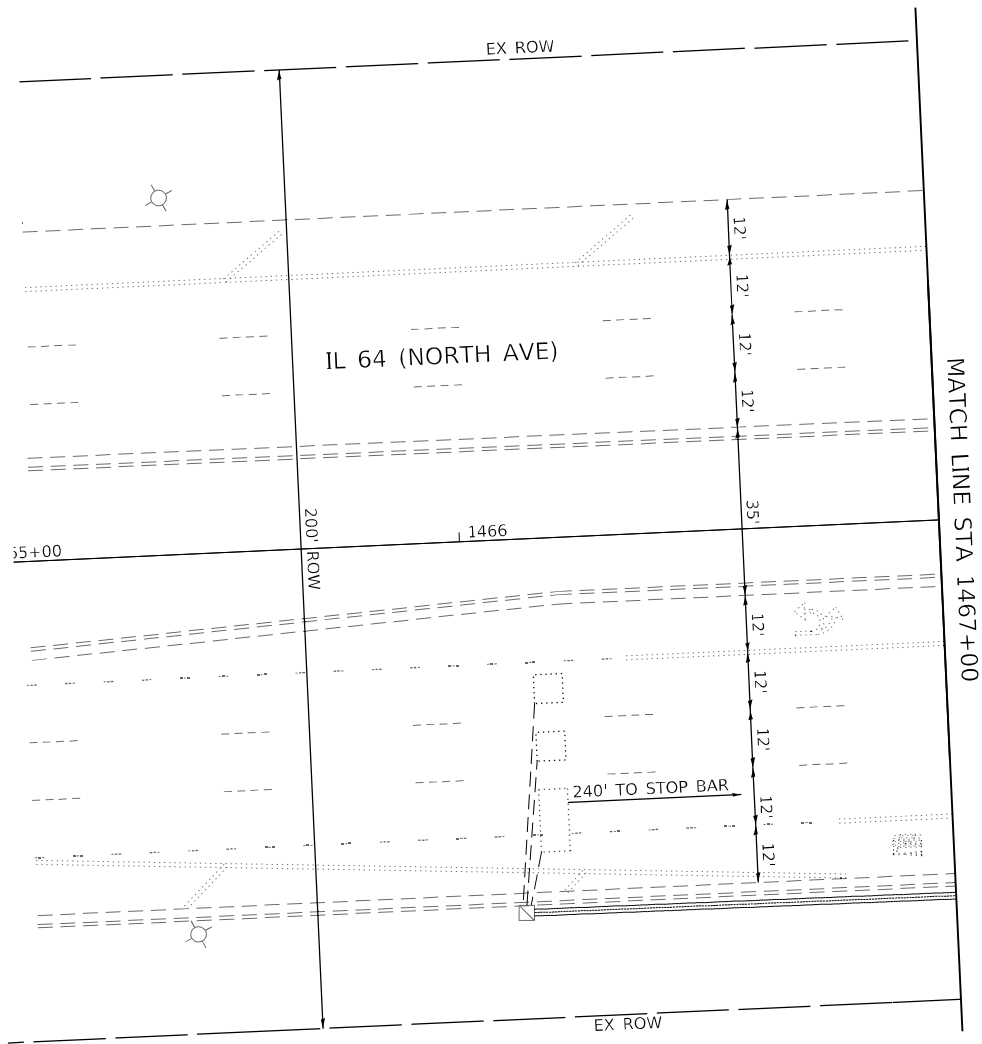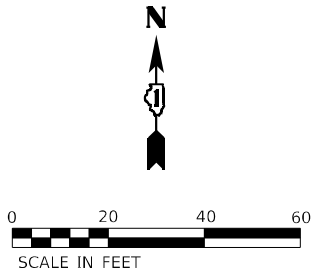

MODEL: Default
FILE NAME: p:\projects\pva\bartley.com\ts\ts-62\pva-01\Documents\01 Active Projects\MW\CHS-168950\00 - IL 64\Phase II\2 Design\CAD\Plan Streets\Signal\West Corridor Signal\01081714-IL-64-KIM.dgn



USER NAME =	DESIGNED -	REVISED -
	DRAWN -	REVISED -
PLOT SCALE =	CHECKED -	REVISED -
PLOT DATE =	DATE -	REVISED -

STATE OF ILLINOIS
DEPARTMENT OF TRANSPORTATION

TRAFFIC SIGNAL MODERNIZATION PLAN
IL 64 (NORTH AVE) AND PRESIDENT ST

SCALE: 1" = 20' SHEET OF SHEETS STA. TO STA.

F.A.P. RTE.	SECTION	COUNTY	TOTAL SHEETS	SHEET NO.
307	2020-263-SUR,SW&TS	DUPAGE	529	187
CONTRACT NO. 62N33				
ILLINOIS FED. AID PROJECT				

TS 21395
IDOT TACTICS
FORMER EAGLE 2E



Kimley»Horn
© 2023 KIMLEY-HORN AND ASSOCIATES, INC.
4201 WHITEFIELD ROAD, SUITE 603
WARRENVILLE, IL 60555
PHONE: 630-487-6550
WWW.KIMLEY-HORN.COM

LEGEND:

- ← (⊗) — PROTECTED PHASE
- ← - (⊗) - PROTECTED/PERMITTED PHASE
- ← - (⊗) → PEDESTRIAN PHASE
- ↶ (⬡) OL OVERLAP



DESIGNED	-
DRAWN	-
CHECKED	-
DATE	-

EX TRACER CABLE
(TO BE ABANDONED)

EX INTERCONNECT
TO SCHMALE RD (TO
BE ABANDONED)

PR LATERAL AND TRACER CABLE
(SEE COMMUNICATION PLANS)

PR CONTROLLER IN-
EX CABINET

- REMOVE AND REPLACE BATTERIES FOR UPS

GM 

**CABLE PLAN, PHASE DESIGNATION DIAGRAM, AND
EMERGENCY VEHICLE PREEMPTION SEQUENCE
IL 64 (NORTH AVE) AND PRESIDENT ST**

SCALE: N.T.S.	SHEET	OF	SHEETS	STA.	TO STA.
---------------	-------	----	--------	------	---------




F.A.P. RTE.	SECTION	COUNTY	TOTAL SHEETS	SHEET NO.
307	2020-263-SUR,SW&TS	DUPAGE	529	188
		CONTRACT NO. 62N33		
ILLINOIS		FED. AID PROJECT		

SIGN PANEL – TYPE 1 OR TYPE 2

ALL DIMENSIONS ARE IN INCHES UNLESS OTHERWISE NOTED



DESIGN SERIES	AREA (SQ FT)	SIGN PANEL TYPE	SHEETING TYPE	QTY. REQUIRED
D	12.5	2	ZZ	2

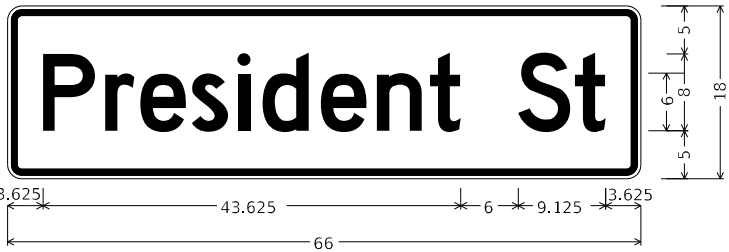

DESIGN SERIES	AREA (SQ FT)	SIGN PANEL TYPE	SHEETING TYPE	QTY. REQUIRED
D	8.25	1	ZZ	2

SCHEDULE OF QUANTITIES

ITEM DESCRIPTION	UNIT	QUANTITY
SIGN PANEL - TYPE 1	SQ FT	46.5
SIGN PANEL - TYPE 2	SQ FT	25.0
UNDERGROUND CONDUIT, GALVANIZED STEEL, 2" DIA.	FOOT	36
UNDERGROUND CONDUIT, GALVANIZED STEEL, 4" DIA.	FOOT	46
MAINTENANCE OF EXISTING TRAFFIC SIGNAL INSTALLATION	EACH	1
ELECTRIC CABLE IN CONDUIT, SIGNAL NO. 14 2C	FOOT	509
ELECTRIC CABLE IN CONDUIT, SIGNAL NO. 14 3C	FOOT	509
ELECTRIC CABLE IN CONDUIT, SIGNAL NO. 14 5C	FOOT	2870
ELECTRIC CABLE IN CONDUIT, SIGNAL NO. 14 7C	FOOT	1052
ELECTRIC CABLE IN CONDUIT, LEAD-IN, NO. 14 1 PAIR	FOOT	1506
ELECTRIC CABLE IN CONDUIT, SERVICE, NO. 6 2 C	FOOT	24
ELECTRIC CABLE IN CONDUIT, EQUIPMENT GROUNDING CONDUCTOR, NO. 6 1C	FOOT	70
TRAFFIC SIGNAL POST, GALVANIZED STEEL 16 FT.	EACH	1
STEEL COMBINATION MAST ARM ASSEMBLY AND POLE 64 FT.	EACH	2
CONCRETE FOUNDATION, TYPE A	FOOT	4
CONCRETE FOUNDATION, TYPE E 42-INCH DIAMETER	FOOT	42
DRILL EXISTING HANDHOLE	EACH	4
SIGNAL HEAD, LED, 1-FACE, 3-SECTION, MAST-ARM MOUNTED	EACH	12
SIGNAL HEAD, LED, 1-FACE, 3-SECTION, BRACKET MOUNTED	EACH	2
SIGNAL HEAD, LED, 1-FACE, 5-SECTION, BRACKET MOUNTED	EACH	2
SIGNAL HEAD, LED, 1-FACE, 5-SECTION, MAST-ARM MOUNTED	EACH	6
PEDESTRIAN SIGNAL HEAD, LED, 1-FACE, BRACKET MOUNTED WITH COUNTDOWN TIMER	EACH	2
TRAFFIC SIGNAL BACKPLATE, LOUVERED, FORMED PLASTIC	EACH	18
INDUCTIVE LOOP DETECTOR	EACH	4
* LIGHT DETECTOR	EACH	4
* LIGHT DETECTOR AMPLIFIER	EACH	1
REMOVE EXISTING TRAFFIC SIGNAL EQUIPMENT	EACH	1
REMOVE EXISTING CONCRETE FOUNDATION	EACH	5
* EMERGENCY VEHICLE PRIORITY SYSTEM LINE SENSOR CABLE, NO. 20 3/C	FOOT	574
SERVICE INSTALLATION, GROUND MOUNTED, METERED	EACH	1
LAYER II (DATALINK) SWITCH	EACH	1
TERMINATE FIBER IN CABINET	EACH	12
PEDESTRIAN SIGNAL POST, 10 FT.	EACH	2
TACTICS LICENSE EXPANSION	EACH	1
FULL-ACTUATED CONTROLLER IN EXISTING CABINET	EACH	1
REMOVE AND REPLACE BATTERIES FOR UNINTERRUPTABLE POWER SUPPLY, EXTENDED	EACH	1
FIBER OPTIC INTERCONNECT CENTER, 48 PORT	EACH	1
ACCESSIBLE PEDESTRIAN SIGNALS	EACH	2
CONCRETE FOUNDATION, TYPE A 12-INCH DIAMETER	FOOT	8
LED SIGNAL FACE, LENS COVER	EACH	22
VIDEO VEHICLE DETECTION SYSTEM, SINGLE APPROACH	EACH	2

* - 100% COST TO THE VILLAGE OF GLENDALE HEIGHTS

TS 21395
IDOT TACTICS
FORMER EAGLE 2E

Model: Default
File: Kimley-Horn-Bentley.com\k-h-gp-d\1\Documents\01 Active Projects\IMW-CL-S-160950\00 - IL 64\Phase 1\12 Design\CAD\Plan_Sheets\Signs\11aWest_Corridor_Signs\BID\009121-1a-rt-ts-38_KH.dgn



© 2023 KIMLEY-HORN AND ASSOCIATES, INC.
4001 HWY 10 ROAD, SUITE 600
WARREN, IL 60555
PHONE: 847.447.4555
WWW.KIMLEY-HORN.COM

USER NAME =	DESIGNED -	REVISED -
	DRAWN -	REVISED -
PLOT SCALE =	CHECKED -	REVISED -
PLOT DATE =	DATE -	REVISED -

STATE OF ILLINOIS
DEPARTMENT OF TRANSPORTATION

MAST ARM MOUNTED STREET NAME SIGNS AND
SCHEDULE OF QUANTITIES
IL 64 (NORTH AVE) AND PRESIDENT ST

SCALE: N.T.S. SHEET OF SHEETS STA. TO STA.

F.A.P. RTE.	SECTION	COUNTY	TOTAL SHEETS	SHEET NO.
307	2020-263-SUR,SW&TS	DUPAGE	529	189
CONTRACT NO. 62N33				
ILLINOIS FED. AID PROJECT				

REMOVAL NOTES


THE FOLLOWING ITEMS SHALL BE REMOVED BY THE CONTRACTOR AND SHALL BE DISPOSED OF BY THEM OUTSIDE THE RIGHT-OF-WAY AT THEIR EXPENSE. THE SALVAGE VALUE OF THE REMOVED EQUIPMENT SHALL BE REFLECTED IN CONTRACT BID PRICE.

- 20 EACH 3-SECTION SIGNAL HEAD
- 4 EACH 5-SECTION SIGNAL HEAD
- 1 EACH CONTROLLER (M52)
- 4 EACH STREET NAME SIGN PANEL
- 14 EACH TRAFFIC SIGNAL BACKPLATE
- 2 EACH COMBINATION DUAL MAST ARM ASSEMBLY AND POLE
- 2 EACH COMBINATION MAST ARM ASSEMBLY AND POLE

RELOCATION NOTES

THE FOLLOWING EXISTING TRAFFIC SIGNAL EQUIPMENT SHALL BE REMOVED BY THE CONTRACTOR, SAFELY STORED AND RELOCATED TO THE PROPOSED MAST ARMS, POSTS, AND TRAFFIC SIGNAL CONTROLLER CABINET.

- 4 EACH CONFIRMATION BEACON
- 4 EACH LIGHT DETECTOR

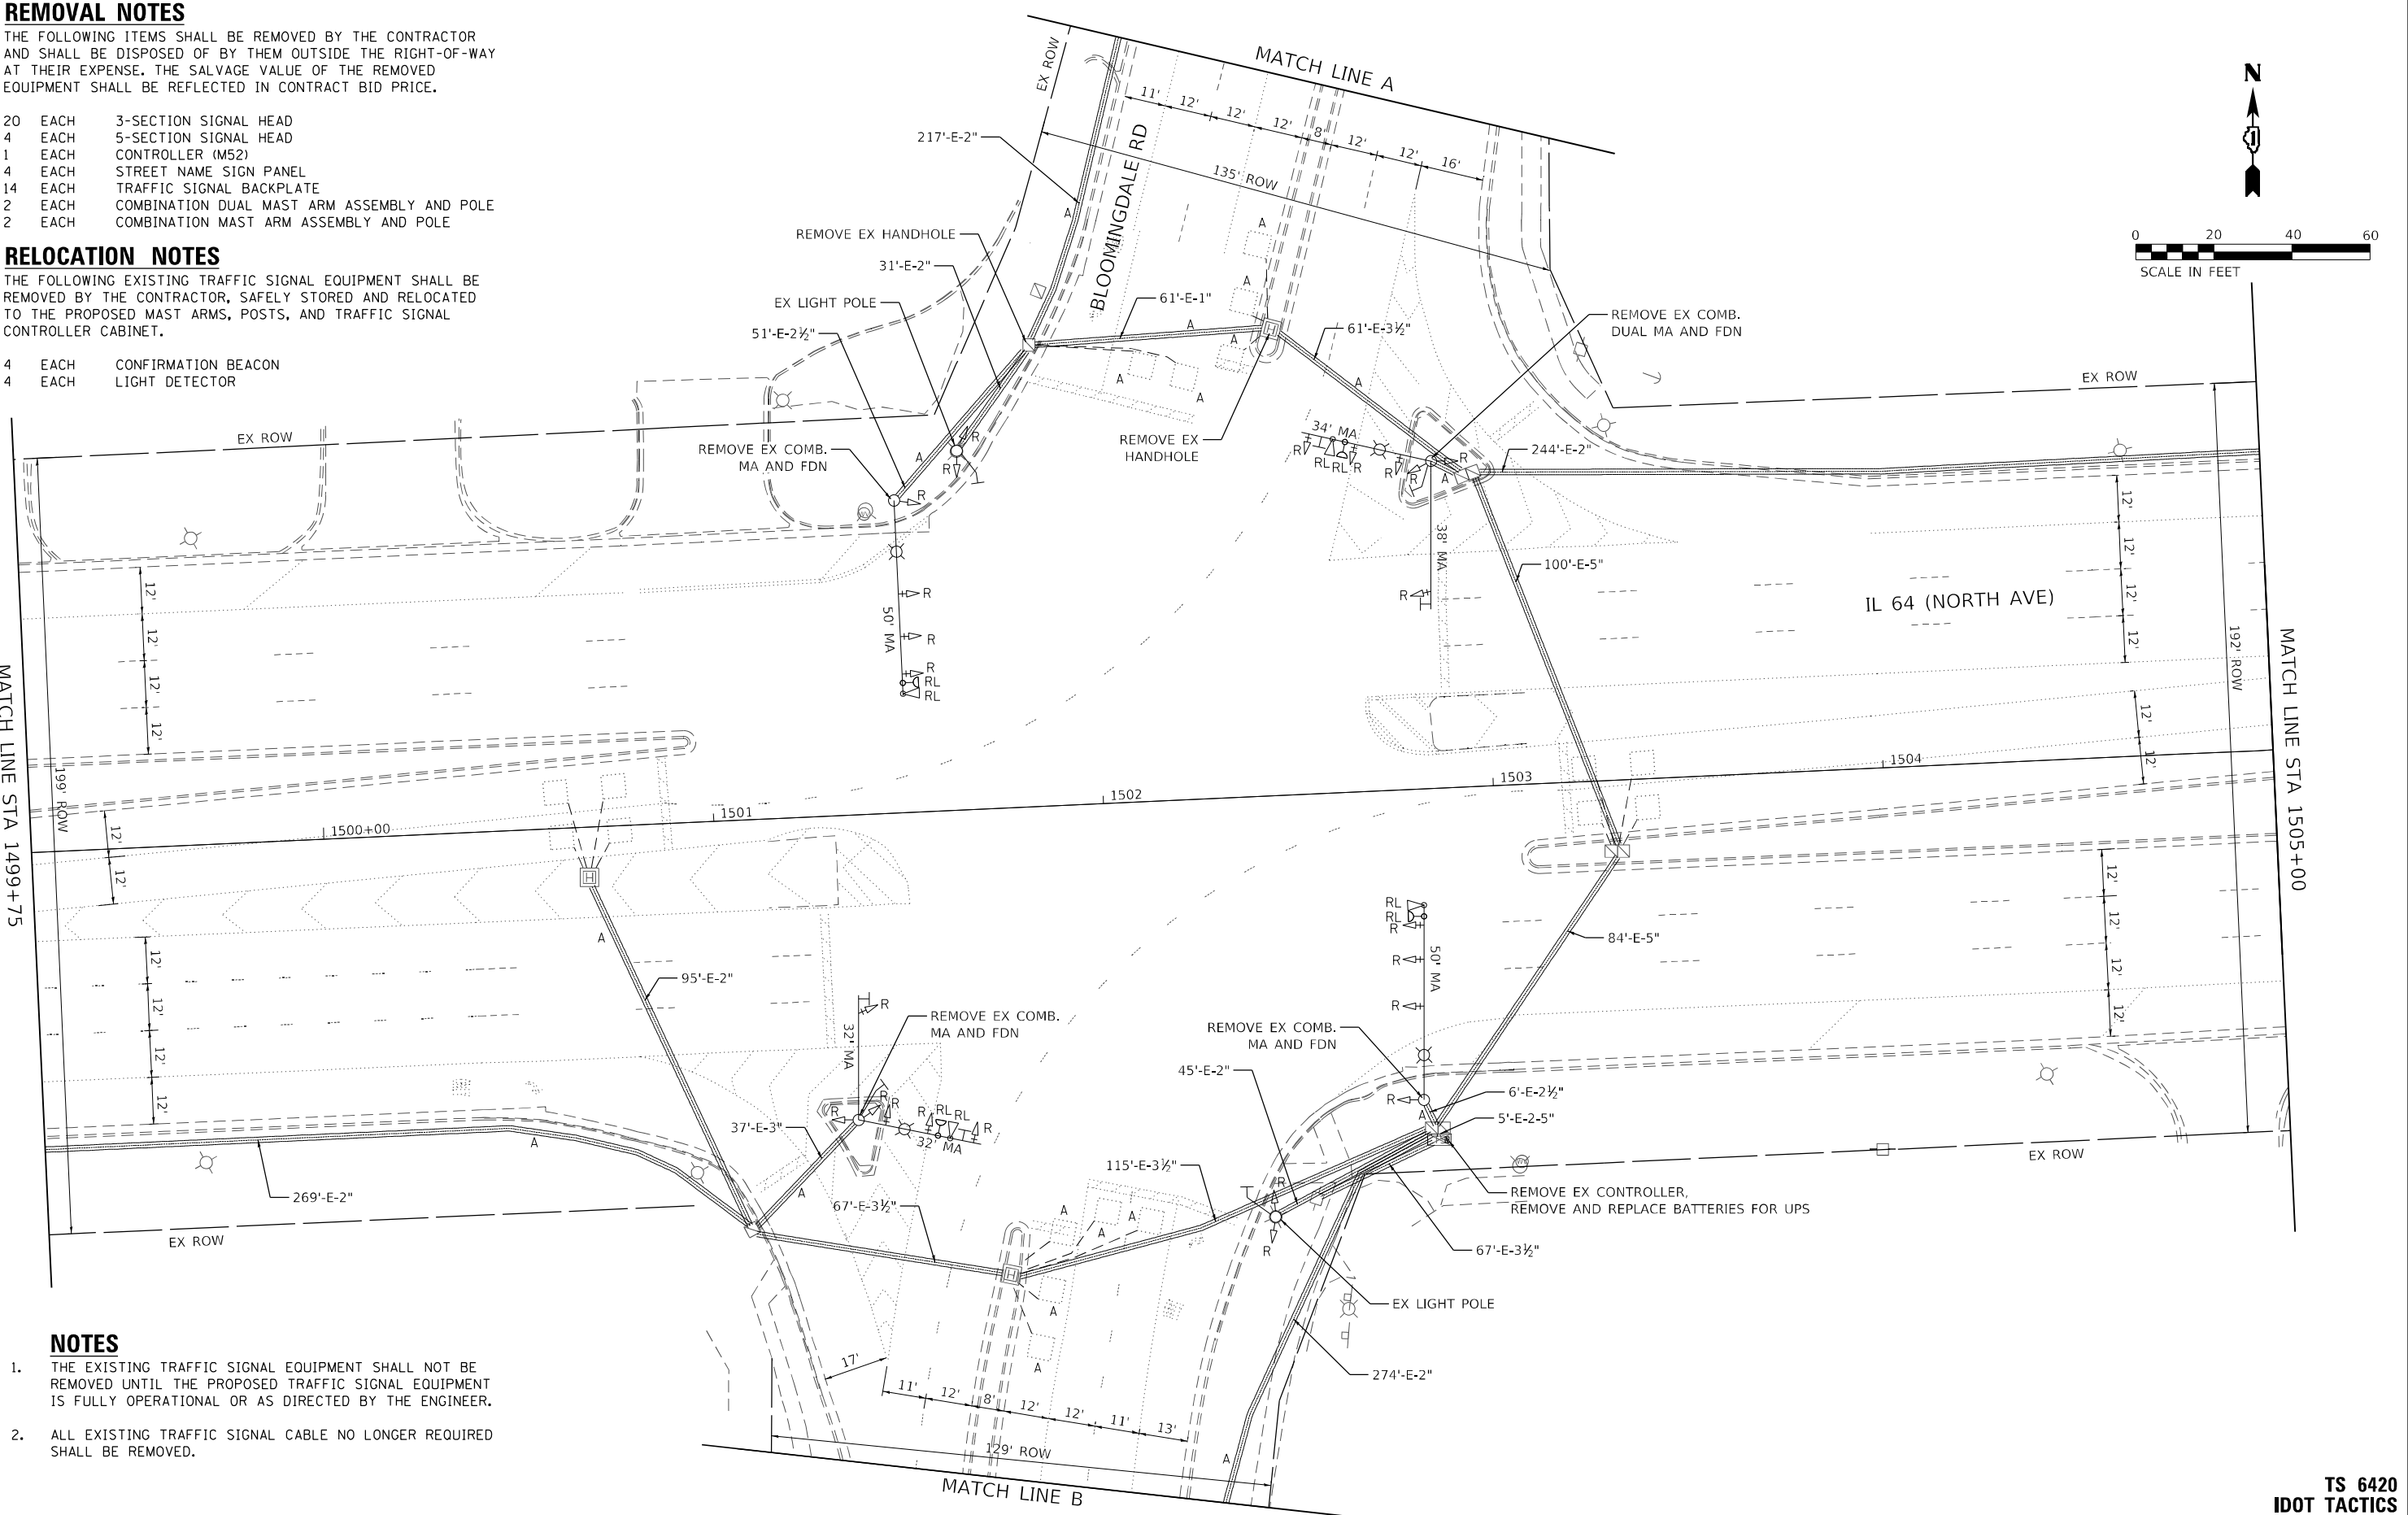

NOTES

- 1. THE EXISTING TRAFFIC SIGNAL EQUIPMENT SHALL NOT BE REMOVED UNTIL THE PROPOSED TRAFFIC SIGNAL EQUIPMENT IS FULLY OPERATIONAL OR AS DIRECTED BY THE ENGINEER.
- 2. ALL EXISTING TRAFFIC SIGNAL CABLE NO LONGER REQUIRED SHALL BE REMOVED.

MODEL: Default
FILE: \\usmc-prod-01-pw-bentley.com\ktp-gp-d1\Documents\01 Active Projects\TMC\CHS-168959\100 - IL 64\Phase II\2 Design\CAD\Plan_Signals\West Corridor_Signals\01081714-IL-64-99_KIM.dgn

KimleyHorn

© 2023 KIMLEY-HORN AND ASSOCIATES, INC.
4001 WILLOW D. ROAD, SUITE 600
WARREN, IL 6. 0555
PHONE: (847) 455-4555
WWW.KIMLEY-HORN.COM

USER NAME =	DESIGNED -	REVISED -
	DRAWN -	REVISED -
PLOT SCALE =	CHECKED -	REVISED -
PLOT DATE =	DATE -	REVISED -

STATE OF ILLINOIS
DEPARTMENT OF TRANSPORTATION

TRAFFIC SIGNAL EQUIPMENT REMOVAL PLAN
IL 64 (NORTH AVE) AND BLOOMINGDALE RD

SCALE: 1" = 20' SHEET OF SHEETS STA. TO STA.

F.A.P. RTE.	SECTION	COUNTY	TOTAL SHEETS	SHEET NO.
307	2020-263-SUR,SW&TS	DUPAGE	529	190
CONTRACT NO. 62N33				
ILLINOIS FED. AID PROJECT				

TS 6420
IDOT TACTICS
FORMER EAGLE 2E

MODEL: Default
FILE: I:\bentley\dwg\ts620\ts620.dgn
PROJECT: I:\bentley\dwg\ts620\ts620.dgn
SHEET: 191
DATE: 10/1/2020
TIME: 10:47:45
USER: JHORN



USER NAME	=	DESIGNED	-
DRAWN	-	REVIS	-
PLOT SCALE	=	CHECKED	-
PLOT DATE	=	DATE	-




STATE OF ILLINOIS
DEPARTMENT OF TRANSPORTATION

TRAFFIC SIGNAL EQUIPMENT REMOVAL PLAN
IL 64 (NORTH AVE) AND BLOOMINGDALE RD

SCALE: 1" = 20' SHEET OF SHEETS STA. TO STA.

F.A.P. RTE.	SECTION	COUNTY	TOTAL SHEETS	SHEET NO.
307	2020-263-SUR,SW&TS	DUPAGE	529	191
CONTRACT NO. 62N33				
ILLINOIS FED. AID PROJECT				

TS 6420
IDOT TACTICS
FORMER EAGLE 2E

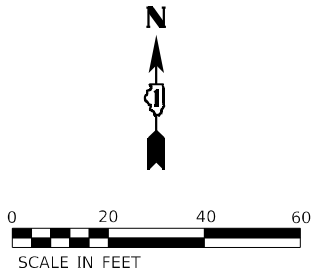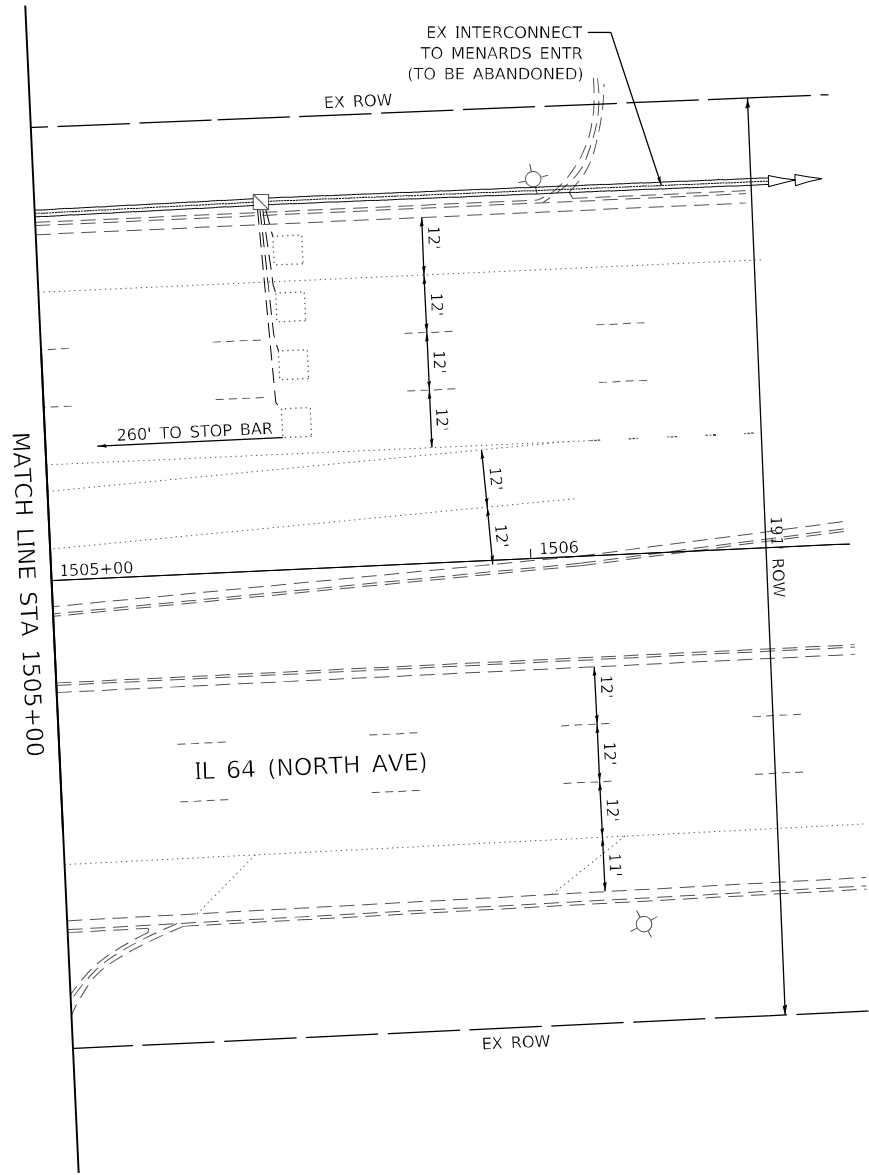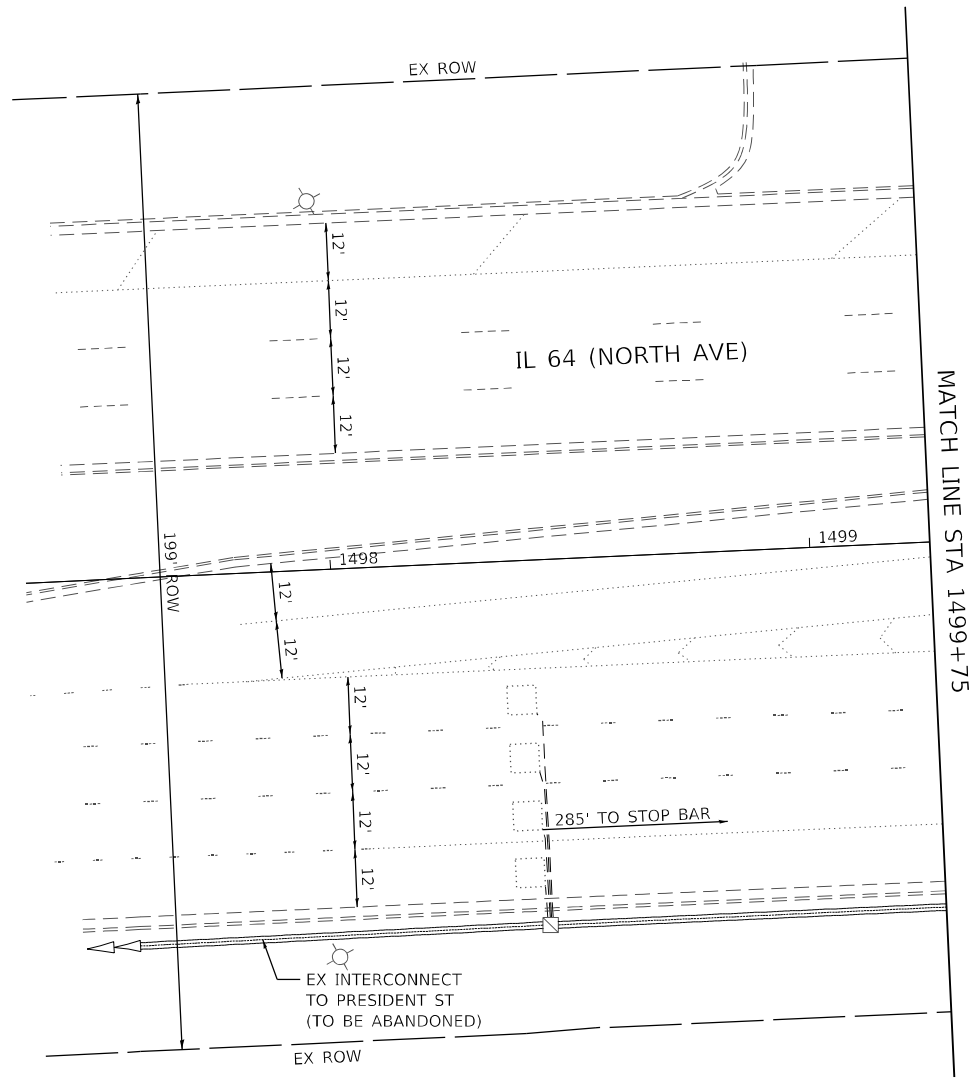

MODEL: Default
FILE NAME: p:\work\paw.bentley.com\k-horn\011\Documents\01 Active Projects\MM\CHS-168959\100 - IL 64\Phase 1112 Design\CAD\Plan Sheets\Signal\West Corridor - Signal\BID1081214\htcs-01_KHA.dgn

Kimley»Horn

© 2023 KIMLEY-HORN AND ASSOCIATES, INC.
4011 WILFORD ROAD, SUITE 100
WARRENVILLE, IL 60055
PHONE: 630.474.6550
WWW.KIMLEY-HORN.COM

USER NAME	=	DESIGNED	-
		DRAWN	-
PLOT SCALE	=	CHECKED	-
PLOT DATE	=	DATE	-

REVISED	-
REVISED	-
REVISED	-
REVISED	-




STATE OF ILLINOIS
DEPARTMENT OF TRANSPORTATION

TRAFFIC SIGNAL EQUIPMENT REMOVAL PLAN
IL 64 (NORTH AVE) AND BLOOMINGDALE RD


SCALE: 1" = 20' SHEET OF SHEETS STA. TO STA.

F.A.P. RTE.	SECTION	COUNTY	TOTAL SHEETS	SHEET NO.
307	2020-263-SUR,SW&TS	DUPAGE	529	192
CONTRACT NO. 62N33				
		ILLINOIS	FED. AID PROJECT	

TS 6420
IDOT TACTICS
FORMER EAGLE 2E

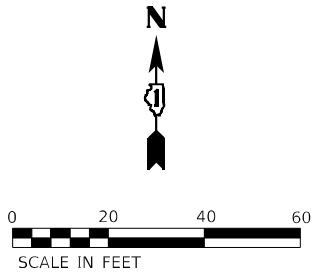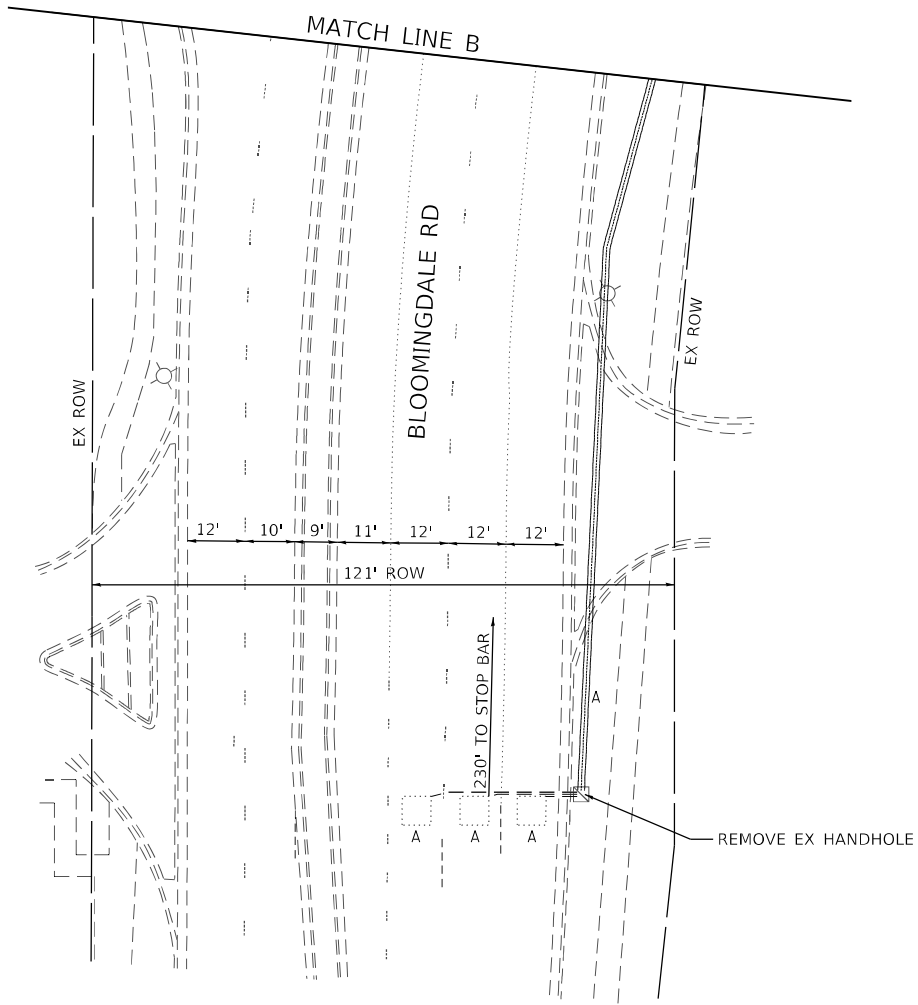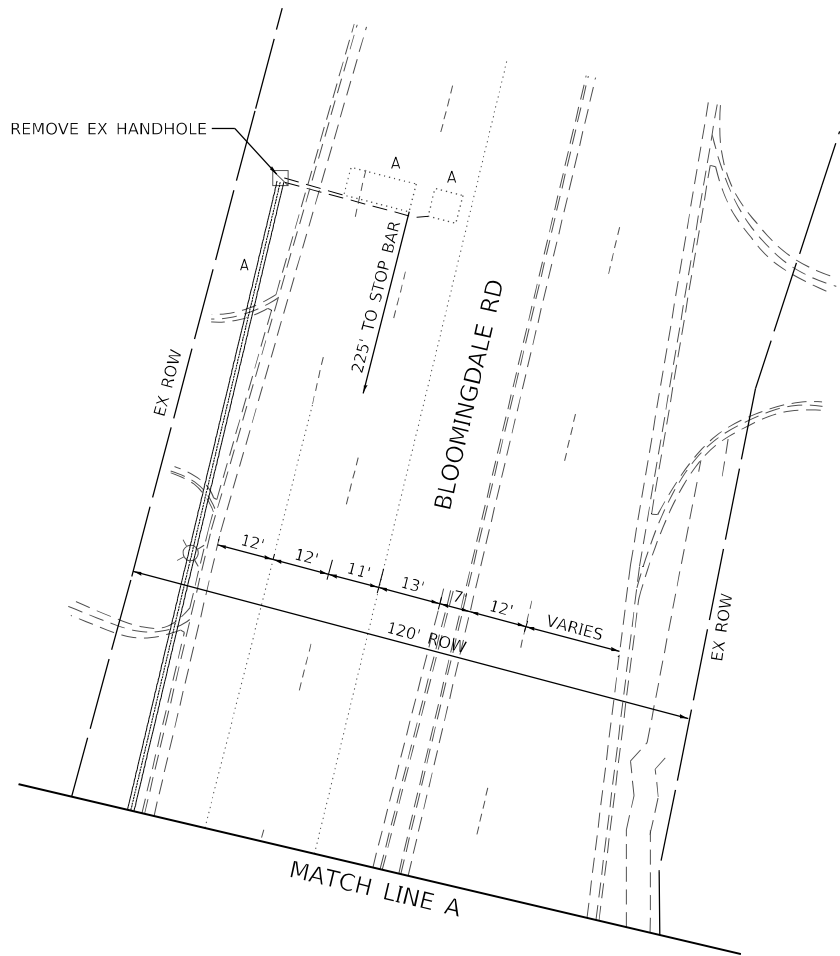

1. ALL PROPOSED TRAFFIC SIGNAL CABLE SHALL BE ROUTED THROUGH THE PROPOSED CONDUIT.
2. A SEPARATE LEAD-IN CABLE SHALL BE INSTALLED FOR THE DETECTOR LOOPS ON IL 64 (NORTH AVE).
3. THERE SHALL BE A MINIMUM OF 4' SIDEWALK CLEARANCE IN FRONT/BEHIND OF THE TRAFFIC SIGNAL FOUNDATIONS TO BE ADA COMPLIANT.
4. THE SIDEWALK CURBS ON ALL QUADRANTS SHALL BE CUT SO THAT THE POST AND MAST ARM FOUNDATIONS ARE FLUSH WITH THE EDGE OF THE SIDEWALK.
5. ALL PUSH BUTTONS SHALL BE APS.
6. THIS LOCATION HAS BEEN DESIGNED TO BE ADA COMPLIANT. ANY DEVIATION FROM THIS PLAN FOR THE POSTS THAT HAVE PEDESTRIAN EQUIPMENT WILL HAVE TO BE APPROVED BY THE ENGINEER TO ENSURE ADA COMPLIANCE.
7. CONTRACTOR SHALL VERIFY THAT THE PLACEMENT OF THE PROPOSED SIGNAL EQUIPMENT ADJACENT TO EXISTING RAMPS MEET ADA REQUIREMENTS. THE ENGINEER SHALL APPROVE THE PROPOSED LOCATIONS OF THE SIGNAL EQUIPMENT BEFORE INSTALLATION.

 

MODEL: Default
FILE NAME: p:\work\pva\bartley\com\khp\pva\01\Documents\01 Active Projects\IMW\CHS-168959\00 - IL 64\Phase II\2 Design\CAD\Plan_Sheets\Signal\West Corridor_Signal\01081714-IL-64.dgn





USER NAME =	DESIGNED -	REVISED -
	DRAWN -	REVISED -
PLOT SCALE =	CHECKED -	REVISED -
PLOT DATE =	DATE -	REVISED -

STATE OF ILLINOIS
DEPARTMENT OF TRANSPORTATION


TRAFFIC SIGNAL MODERNIZATION PLAN IL 64 (NORTH AVE) AND BLOOMINGDALE RD			
SCALE: 1" = 20'	SHEET	OF	SHEETS
	STA.	TO	STA.

F.A.P. RTE.	SECTION	COUNTY	TOTAL SHEETS	SHEET NO.
307	2020-263-SUR,SW&TS	DUPAGE	529	194
CONTRACT NO. 62N33				
ILLINOIS		FED. AID PROJECT		


TS 6420
IDOT TACTICS
FORMER EAGLE 2E

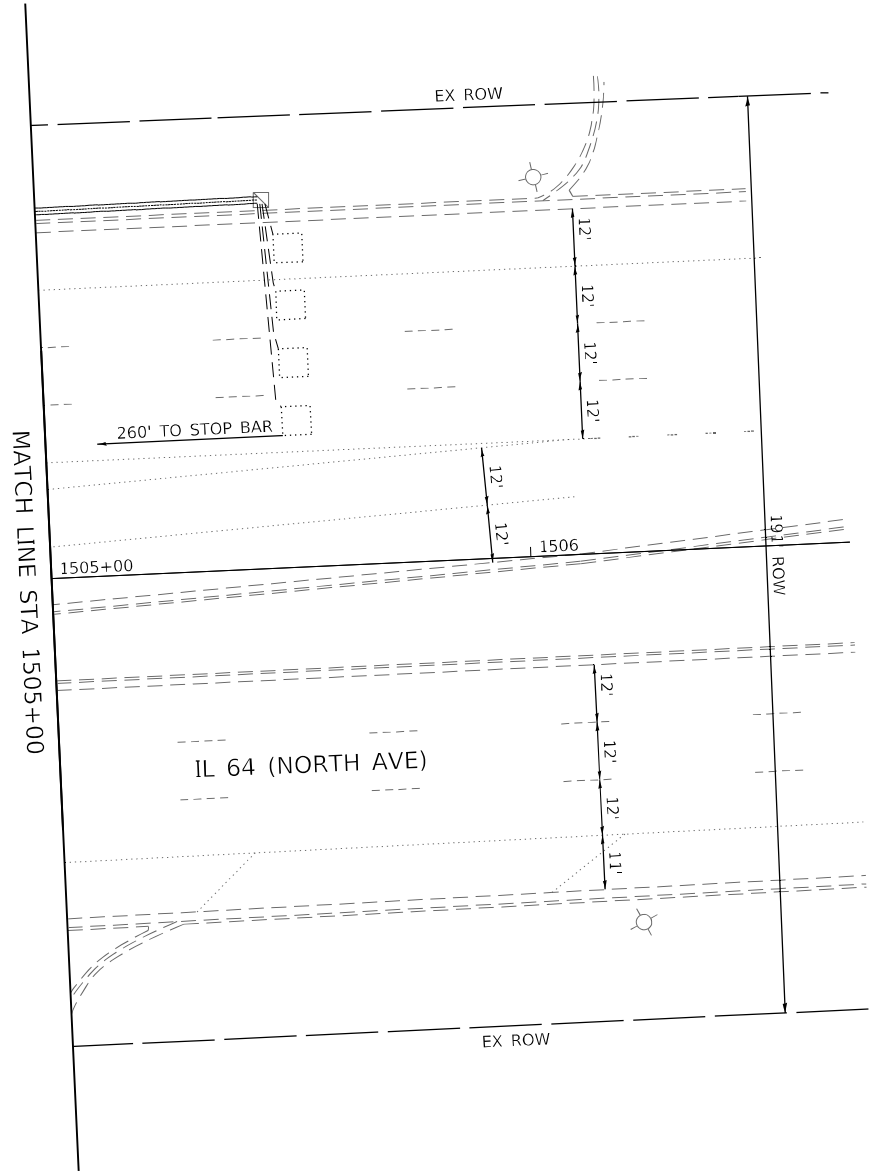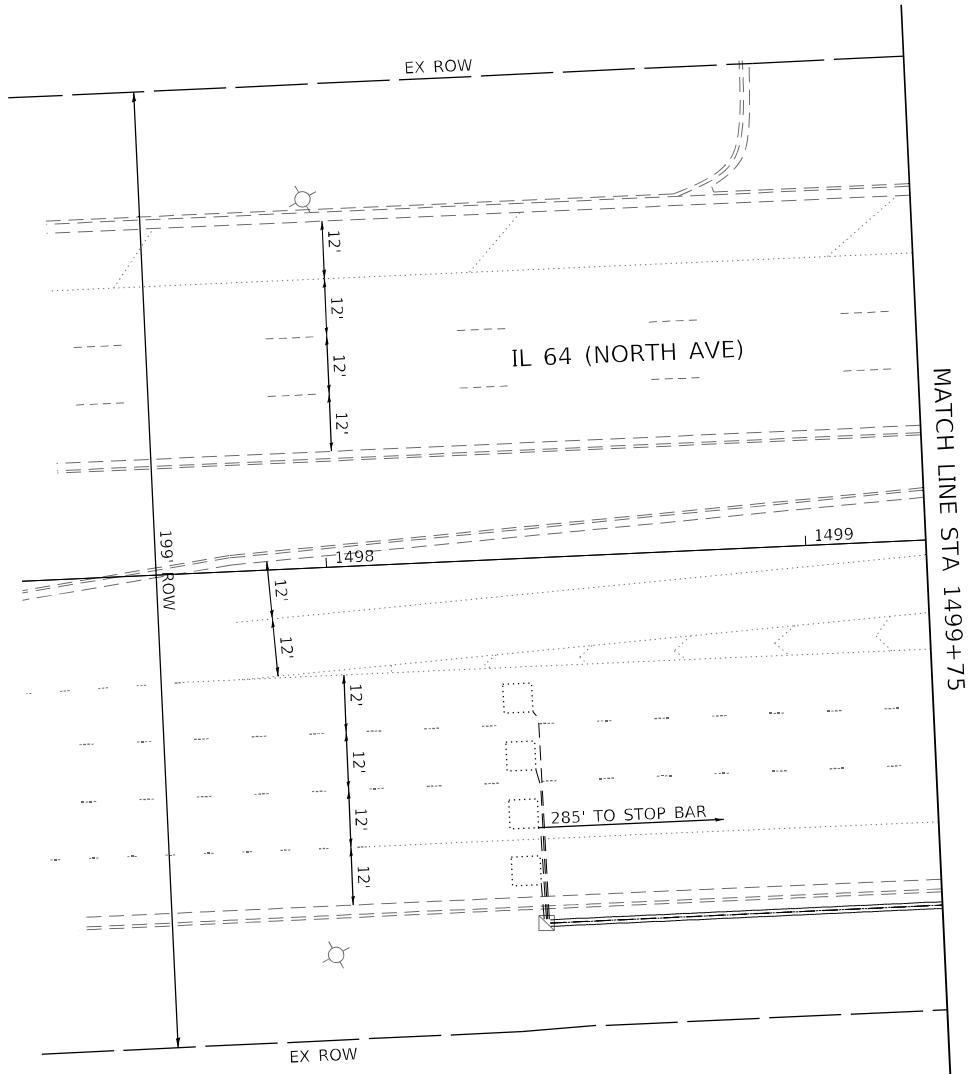

EXISTING CONTROLLER SEQUENCE

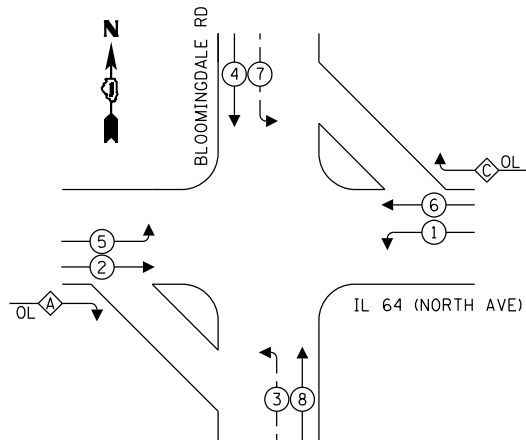


PROPOSED
CONTROLLER SEQUENCE

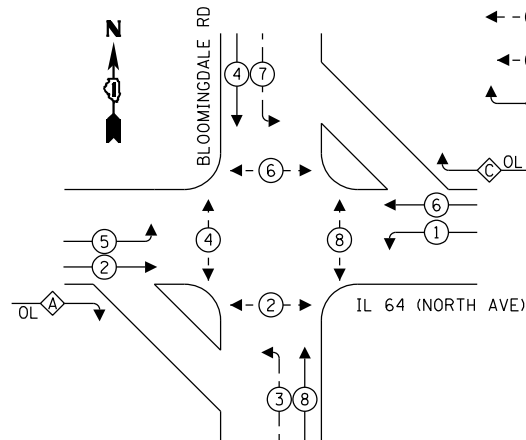

LEGEND:

-  PROTECTED PHASE
 PROTECTED/PERMITTED PHASE
 PEDESTRIAN PHASE
 OVERLAP

EXISTING AND PROPOSED EMERGENCY VEHICLE PREEMPTION SEQUENCE

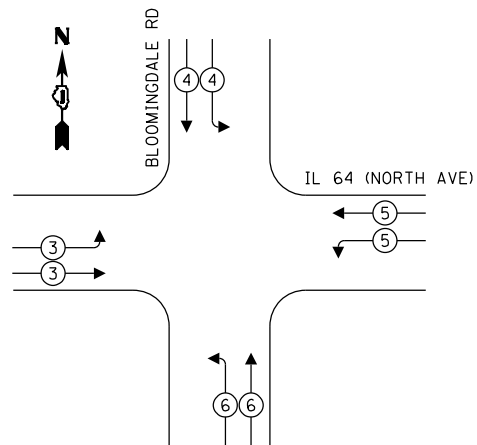

TRAFFIC SIGNAL ELECTRICAL SERVICE REQUIREMENTS


TYPE	QUANTITY	UNIT WATTAGE	TOTAL WATTAGE
SIGNAL HEAD 1 OR 3-SECTION	22	11	242
4-SECTION	-	14	-
5-SECTION	4	13	52
PROGRAMMABLE 3-SECTION	-	22	-
4-SECTION	-	32	-
5-SECTION	-	28	-
PEDESTRIAN SIGNAL	12	15	180
CONTROLLER	1	150	150
MASTER CONTROLLER	-	100	-
UPS	1	25	25
DETECTION VIDEO	2	20	40
BLANK-OUT SIGN	-	25	-
NETWORK SWITCH LAYER II OR III	1	35	35
CELLULAR MODEM	-	15	-
PTZ	1	75	75
TOTAL UPS SIZING			799
UPS CHARGING	1	225	225
BATTERY HEATER MAT	1	180	180
CABINET HEATER	1	200	200
FLASHER	-	15	-
LED STREET NAME SIGN	-	120	-
LUMINAIRE	-	240	-
TOTAL SERVICE WIRE SIZING			1404

ENERGY COSTS TO:
ILLINOIS DEPARTMENT OF TRANSPORTATION
201 W CENTER CT
SCHAUMBURG, IL 60196

ENERGY SUPPLY: COMPANY: COMED
PHONE: (866) 639-3532
ACCOUNT NUMBER: 60180-18058

LEGEND:

* = ROADWAY LIGHTING CABLE

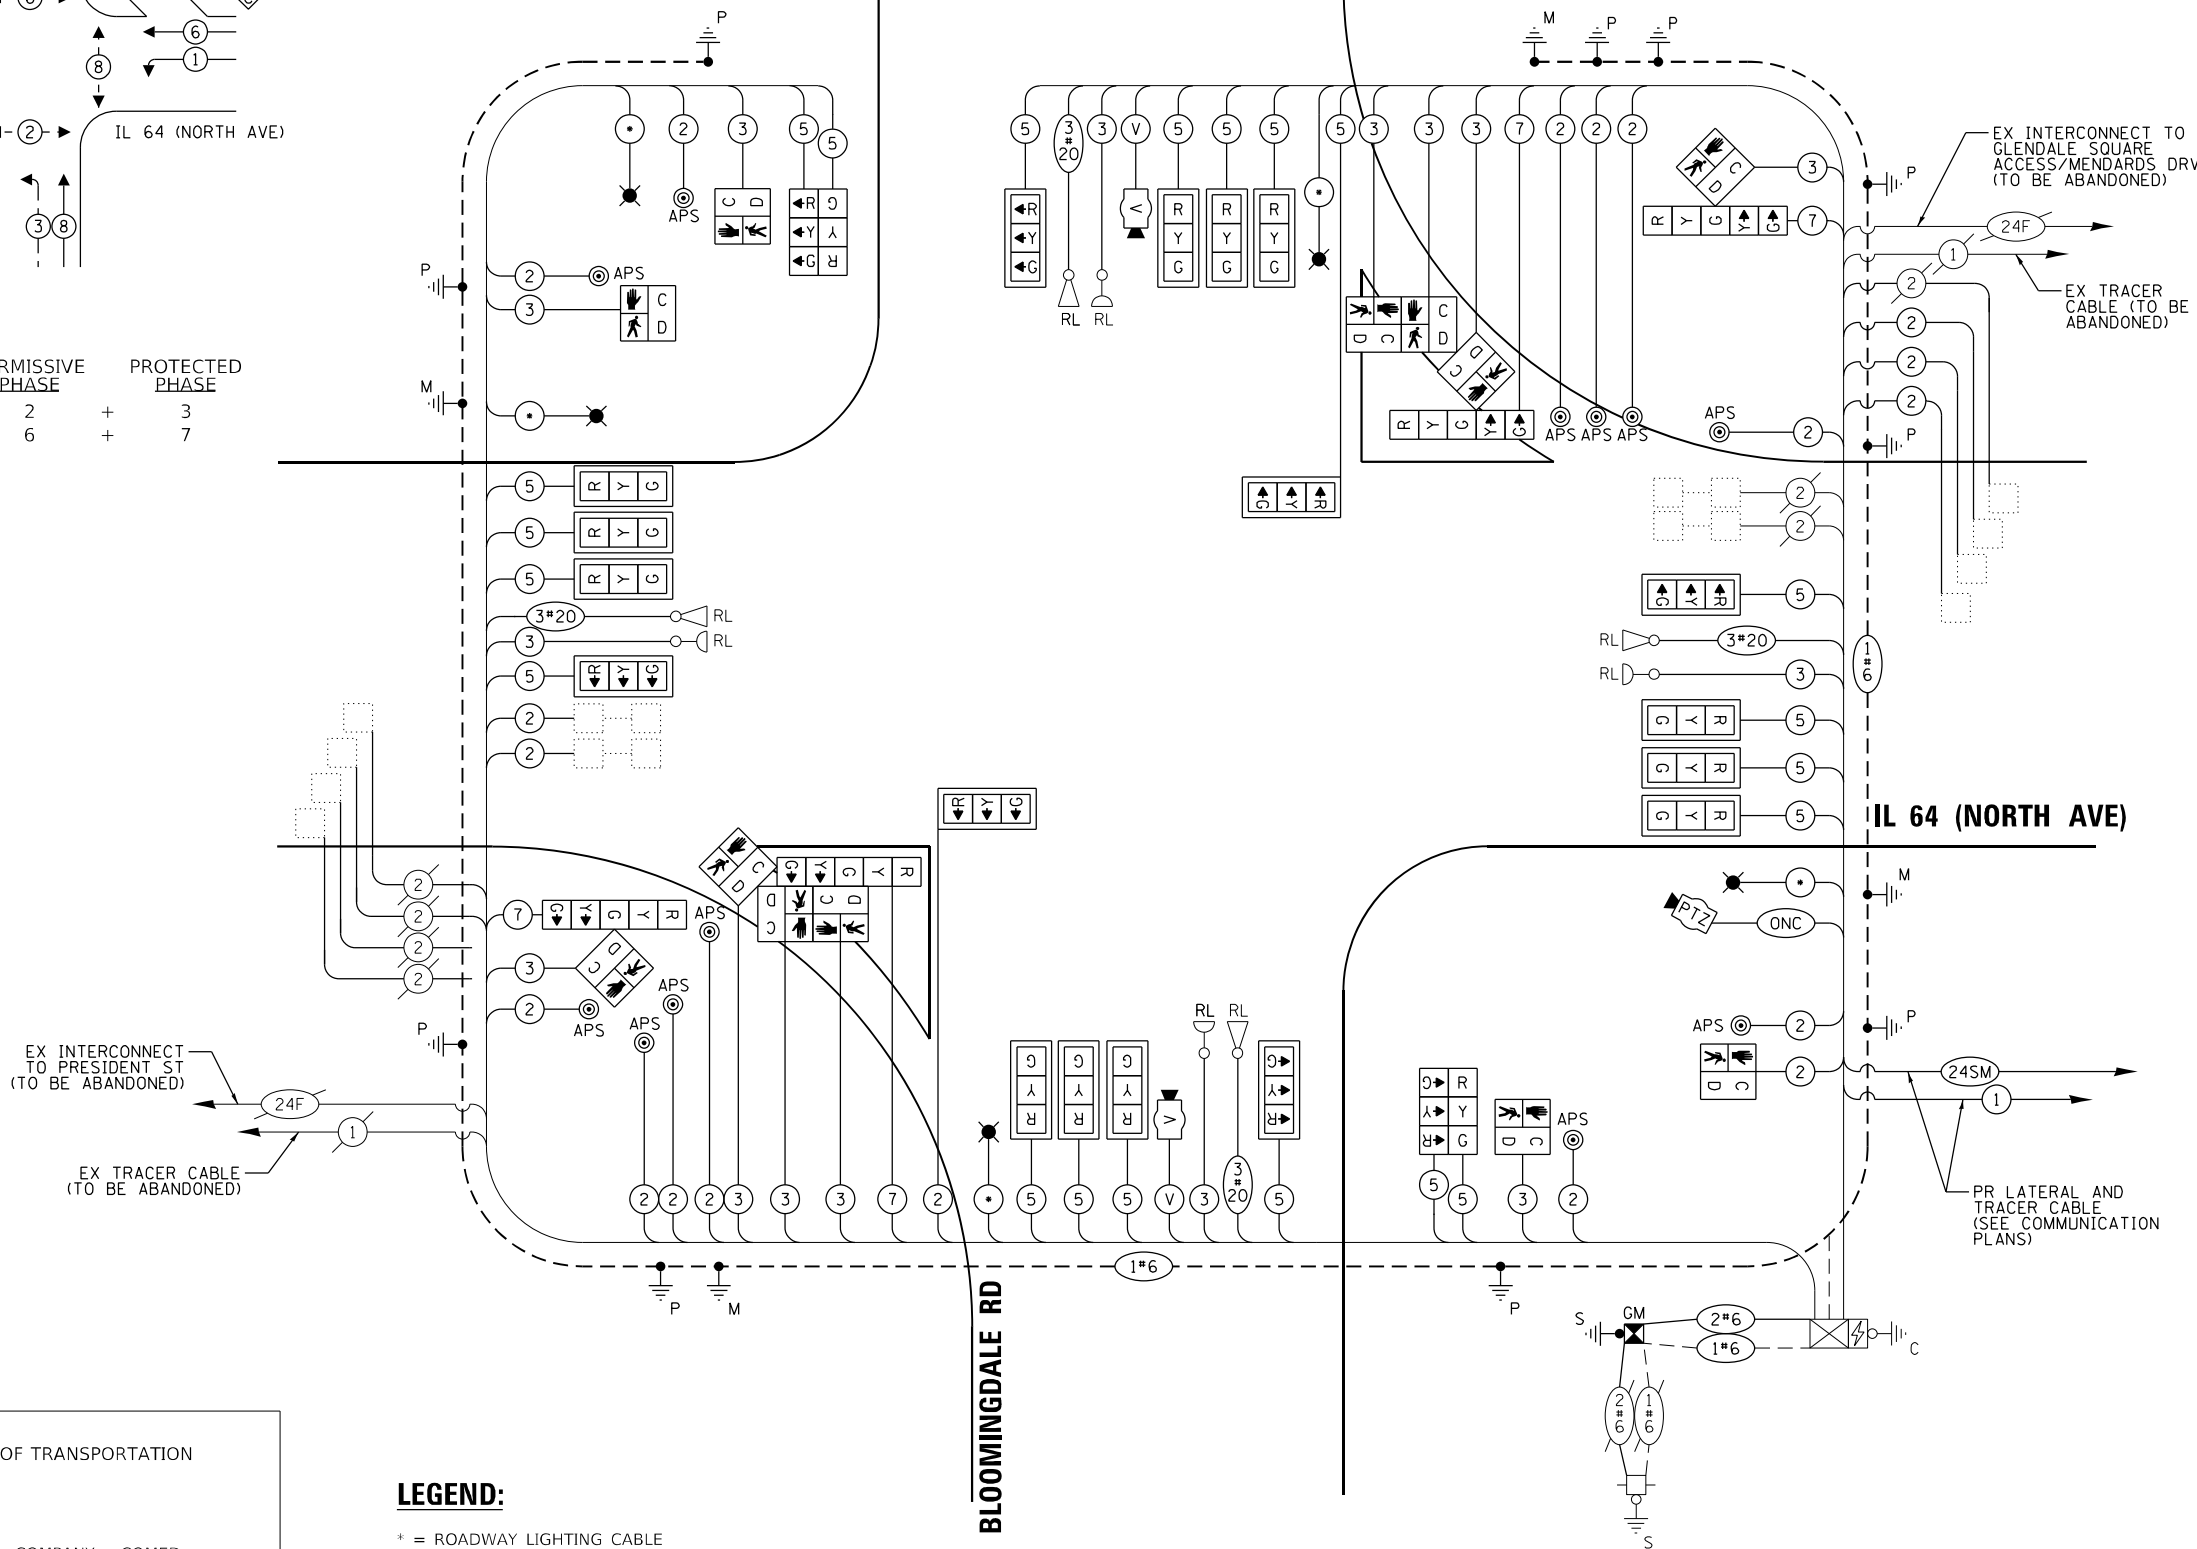

CABLE PLAN

(NOT TO SCALE)

**CABLE PLAN, PHASE DESIGNATION DIAGRAM, AND
EMERGENCY VEHICLE PREEMPTION SEQUENCE
IL 64 (NORTH AVE) AND BLOOMINGDALE RD**

SCALE:	SHEET	OF	SHEETS	STA.	TO STA.
--------	-------	----	--------	------	---------


TS 6420
IDOT TACTICS
FORMER EAGLE 2E

[illegible]

MODEL: Default
FILE NAME: pw:\k-f-pw.bentlev.com\kh-pw-01\Documents\01 Active Projects\MW-CHS-169959\100 - IL 64\Phase II\2 Design\CAD\plan Sheets\Sigsal\West Corridor Signals\010812 L-sht-ts-94 KHA.dgn

SIGN PANEL – TYPE 2

ALL DIMENSIONS ARE IN INCHES UNLESS OTHERWISE NOTED

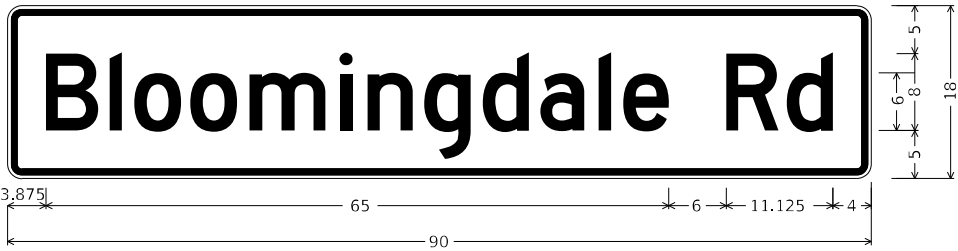

DESIGN SERIES	AREA (SQ FT)	SIGN PANEL TYPE	SHEETING TYPE	QTY. REQUIRED
D	11.25	2	ZZ	2



DESIGN SERIES	AREA (SQ FT)	SIGN PANEL TYPE	SHEETING TYPE	QTY. REQUIRED
D	12.5	2	ZZ	2

SCHEDULE OF QUANTITIES

ITEM DESCRIPTION	UNIT	QUANTITY
SIGN PANEL - TYPE 1	SQ FT	60
SIGN PANEL - TYPE 2	SQ FT	47.5
UNDERGROUND CONDUIT, GALVANIZED STEEL, 2" DIA.	FOOT	131
UNDERGROUND CONDUIT, GALVANIZED STEEL, 3" DIA.	FOOT	180
UNDERGROUND CONDUIT, GALVANIZED STEEL, 4" DIA.	FOOT	1143
HANDHOLE	EACH	2
DOUBLE HANDHOLE	EACH	2
MAINTENANCE OF EXISTING TRAFFIC SIGNAL INSTALLATION	EACH	1
ELECTRIC CABLE IN CONDUIT, SIGNAL NO. 14 2C	FOOT	3321
ELECTRIC CABLE IN CONDUIT, SIGNAL NO. 14 3C	FOOT	5064
ELECTRIC CABLE IN CONDUIT, SIGNAL NO. 14 5C	FOOT	7219
ELECTRIC CABLE IN CONDUIT, SIGNAL NO. 14 7C	FOOT	1253
ELECTRIC CABLE IN CONDUIT, LEAD-IN, NO. 14 1 PAIR	FOOT	1815
ELECTRIC CABLE IN CONDUIT, SERVICE, NO. 6 2 C	FOOT	40
ELECTRIC CABLE IN CONDUIT, EQUIPMENT GROUNDING CONDUCTOR, NO. 6 1C	FOOT	1494
TRAFFIC SIGNAL POST, GALVANIZED STEEL 16 FT.	EACH	4
STEEL MAST ARM ASSEMBLY AND POLE WITH DUAL MAST ARMS, 22 FT. AND 54 FT.	EACH	1
STEEL MAST ARM ASSEMBLY AND POLE WITH DUAL MAST ARMS, 30 FT. AND 54 FT.	EACH	1
STEEL COMBINATION MAST ARM ASSEMBLY AND POLE 75 FT.	EACH	2
CONCRETE FOUNDATION, TYPE A	FOOT	20
CONCRETE FOUNDATION, TYPE E 36-INCH DIAMETER	FOOT	32
CONCRETE FOUNDATION, TYPE E 42-INCH DIAMETER	FOOT	50
DRILL EXISTING HANDHOLE	EACH	13
SIGNAL HEAD, LED, 1-FACE, 3-SECTION, MAST-ARM MOUNTED	EACH	18
SIGNAL HEAD, LED, 1-FACE, 3-SECTION, BRACKET MOUNTED	EACH	4
SIGNAL HEAD, LED, 1-FACE, 5-SECTION, BRACKET MOUNTED	EACH	2
PEDESTRIAN SIGNAL HEAD, LED, 1-FACE, BRACKET MOUNTED WITH COUNTDOWN TIMER	EACH	12
TRAFFIC SIGNAL BACKPLATE, LOUVERED, FORMED PLASTIC	EACH	18
INDUCTIVE LOOP DETECTOR	EACH	5
RELOCATE EXISTING EMERGENCY VEHICLE PRIORITY SYSTEM, DETECTOR UNIT	EACH	4
* REMOVE ELECTRIC CABLE FROM CONDUIT	FOOT	16857
REMOVE EXISTING TRAFFIC SIGNAL EQUIPMENT	EACH	1
REMOVE EXISTING HANDHOLE	EACH	4
REMOVE EXISTING CONCRETE FOUNDATION	EACH	4
CLOSED CIRCUIT TELEVISION DOME CAMERA, HD	EACH	1
* EMERGENCY VEHICLE PRIORITY SYSTEM LINE SENSOR CABLE, NO. 20 3/C	FOOT	1351
OUTDOOR RATED NETWORK CABLE	FOOT	135
SERVICE INSTALLATION, GROUND MOUNTED, METERED	EACH	1
REMOTE CONTROLLED VIDEO SYSTEM	EACH	1
LAYER II (DATALINK) SWITCH	EACH	1
TERMINATE FIBER IN CABINET	EACH	12
PEDESTRIAN SIGNAL POST, 10 FT.	EACH	2
PEDESTRIAN SIGNAL POST, 5 FT.	EACH	4
TACTICS LICENSE EXPANSION	EACH	1
FULL-ACTUATED CONTROLLER IN EXISTING CABINET	EACH	1
REMOVE AND REPLACE BATTERIES FOR UNINTERRUPTABLE POWER SUPPLY, EXTENDED	EACH	1
FIBER OPTIC INTERCONNECT CENTER, 48 PORT	EACH	1
ACCESSIBLE PEDESTRIAN SIGNALS	EACH	12
CONCRETE FOUNDATION, TYPE A 12-INCH DIAMETER	FOOT	24
LED SIGNAL FACE, LENS COVER	EACH	26
VIDEO VEHICLE DETECTION SYSTEM, SINGLE APPROACH	EACH	2
CAMERA MOUNTING ASSEMBLY	EACH	1

* - 100% COST TO THE VILLAGE OF GLENDALE HEIGHTS

TS 6420
IDOT TACTICS
FORMER EAGLE 2E

MODEL: Default
FILE: \\kimley-horn-bentley.com\kjb\p4-d1\Documents\01 Active Projects\WW-CIS-68959\00 - IL 64\Phase II\2 Design\CAD\Plan_Sheets\Sign\West Corridor_Signs\BID 108171-Int-ts-95_KHA.dgn



© 2021 KIMLEY-HORN AND ASSOCIATES, INC.
4001 HWY 10, SUITE 600
WARREN, IL 60555
PHONE: 847-467-4600
WWW.KIMLEY-HORN.COM

USER NAME =	DESIGNED -	REVISED -
	DRAWN -	REVISED -
PLOT SCALE =	CHECKED -	REVISED -
PLOT DATE =	DATE -	REVISED -


STATE OF ILLINOIS
DEPARTMENT OF TRANSPORTATION

MAST ARM MOUNTED STREET NAME SIGNS AND
SCHEDULE OF QUANTITIES
IL 64 (NORTH AVE) AND BLOOMINGDALE RD

SCALE: N.T.S. SHEET OF SHEETS STA. TO STA.

F.A.P. RTE.	SECTION	COUNTY	TOTAL SHEETS	SHEET NO.
307	2020-263-SUR, SW&TS	DUPAGE	529	196
CONTRACT NO. 62N33				
ILLINOIS FED. AID PROJECT				

1. THE EXISTING TRAFFIC SIGNAL EQUIPMENT SHALL NOT BE REMOVED UNTIL THE PROPOSED TRAFFIC SIGNAL EQUIPMENT IS FULLY OPERATIONAL OR AS DIRECTED BY THE ENGINEER.
2. ALL EXISTING TRAFFIC SIGNAL CABLE NO LONGER REQUIRED SHALL BE REMOVED.

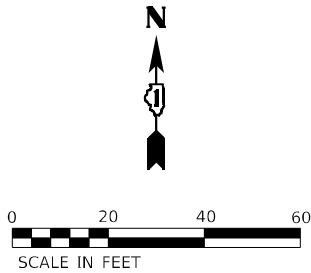

THE FOLLOWING ITEMS SHALL BE REMOVED BY THE CONTRACTOR AND SHALL BE DISPOSED OF BY THEM OUTSIDE THE RIGHT-OF-WAY AT THEIR EXPENSE. THE SALVAGE VALUE OF THE REMOVED EQUIPMENT SHALL BE REFLECTED IN CONTRACT BID PRICE.

14	EACH	SIGNAL HEAD, 1 FACE, 3 SECTION
8	EACH	SIGNAL HEAD, 1 FACE, 5 SECTION
1	EACH	CONTROLLER (M52)
4	EACH	CONFIRMATION BEACON
4	EACH	LIGHT DETECTOR
1	EACH	LIGHT DETECTOR AMPLIFIER
12	EACH	TRAFFIC SIGNAL BACKPLATE
2	EACH	TRAFFIC SIGNAL POST
2	EACH	COMBINATION MAST ARM ASSEMBLY AND POLE
2	EACH	COMBINATION DUAL MAST ARM ASSEMBLY AND POLE

TS 11390
IDOT TACTICS
FORMER EAGLE 2E



USER NAME =	DESIGNED -	REVISED -
	DRAWN -	REVISED -
PLOT SCALE =	CHECKED -	REVISED -
PLOT DATE =	DATE -	REVISED -

**STATE OF ILLINOIS
DEPARTMENT OF TRANSPORTATION**

TRAFFIC SIGNAL EQUIPMENT REMOVAL PLAN
IL 64 (NORTH AVE) AND GLENDALE SQUARE ACCESS / MENARDS ENTR

SCALE: 1" = 20'	SHEET	OF	SHEETS	STA.	TO STA.
-----------------	-------	----	--------	------	---------

F.A.P. RTE.	SECTION	COUNTY	TOTAL SHEETS	SHEET NO.
307	2020-263-SUR,SW&TS	DUPAGE	529	197
		CONTRACT NO. 62N33		
ILLINOIS		FED. AID PROJECT		

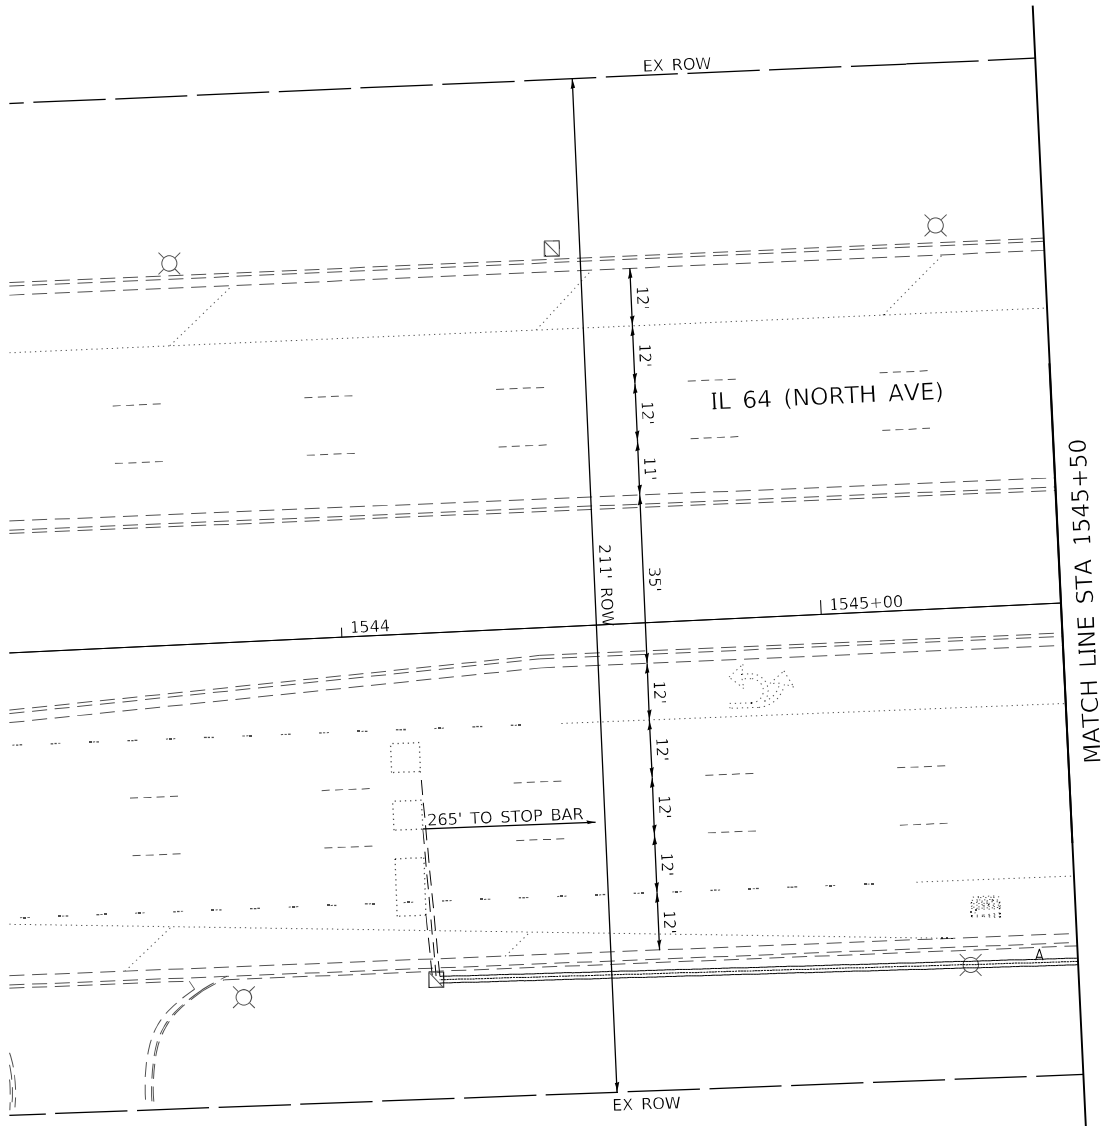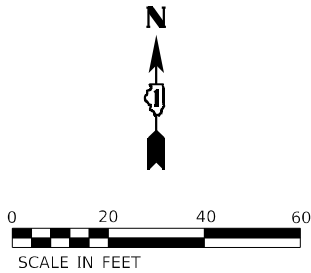

MODEL: Default
FILE NAME: p:\sub-pw\bartley.com\k-h-pw-d1\Documents\01 Active Projects\MW\CL-S-160950\00 - IL 64\Phase 1\12 Design\CAD\Plan Sheets\Signal\West Corridor_Signal\01-12-14-15-27_K44.dgn





USER NAME =	DESIGNED -	REVISED -
	DRAWN -	REVISED -
PLOT SCALE =	CHECKED -	REVISED -
PLOT DATE =	DATE -	REVISED -

STATE OF ILLINOIS
DEPARTMENT OF TRANSPORTATION

TRAFFIC SIGNAL EQUIPMENT REMOVAL PLAN			
IL 64 (NORTH AVE) AND GLENDALE SQUARE ACCESS / MENARDS ENTR			
SCALE: 1" = 20'	SHEET	OF SHEETS	STA. TO STA.

F.A.P. RTE.	SECTION	COUNTY	TOTAL SHEETS	SHEET NO.
307	2020-263-SUR,SW&TS	DUPAGE	529	198
CONTRACT NO. 62N33				
		ILLINOIS	FED. AID PROJECT	

TS 11390
IDOT TACTICS
FORMER EAGLE 2E

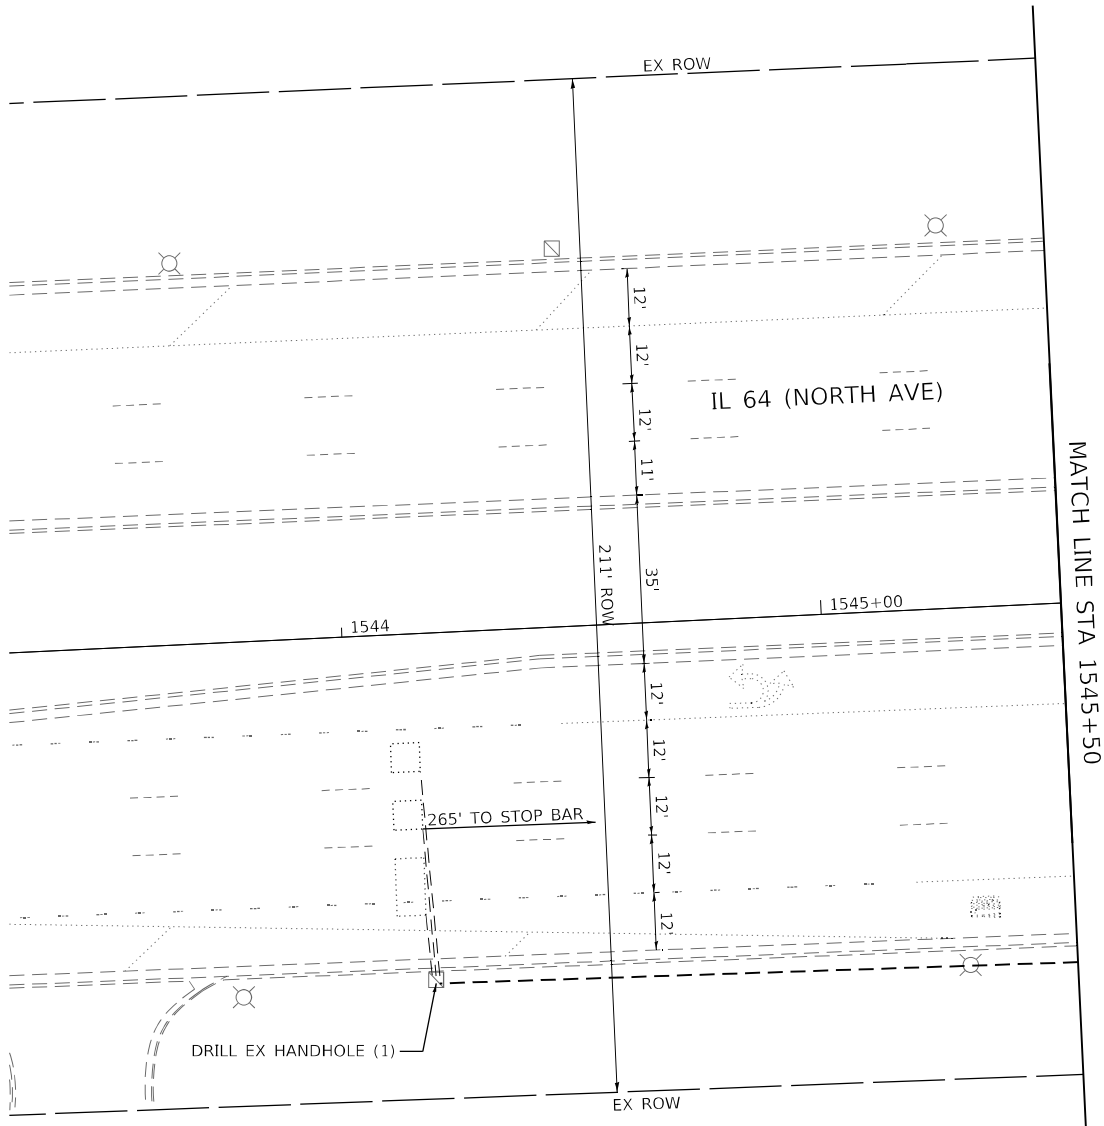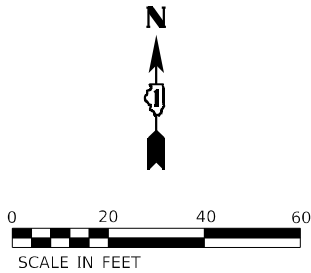

MODEL: Default
FILE: h:\mhc\projects\pva\bartley.com\h-pva-d1\Documents\01 Active Projects\MW\CHS-168950\00 - IL 64\Phase II\2 Design\CAD\Plan_Sheets\Signal\West_Corridor_Signal\01081714-IL-64-99_K4A.dgn



USER NAME =	DESIGNED -	REVISED -
	DRAWN -	REVISED -
PLOT SCALE =	CHECKED -	REVISED -
PLOT DATE =	DATE -	REVISED -

STATE OF ILLINOIS
DEPARTMENT OF TRANSPORTATION

TRAFFIC SIGNAL MODERNIZATION PLAN			
IL 64 (NORTH AVE) AND GLENDALE SQUARE ACCESS / MENARDS ENTR			
SCALE: 1" = 20'	SHEET	OF SHEETS	STA. TO STA.

F.A.P. RTE.	SECTION	COUNTY	TOTAL SHEETS	SHEET NO.
307	2020-263-SUR,SW&TS	DUPAGE	529	200
CONTRACT NO. 62N33				
ILLINOIS FED. AID PROJECT				

TS 11390
IDOT TACTICS
FORMER EAGLE 2E