

TS SHT NO. 152

NOTES:  
1. ALL DIMENSIONS ARE IN FEET AND INCHES.  
2. ALL DIMENSIONS ARE TO FACE UNLESS NOTED OTHERWISE.


| TRAFFIC SIGNAL ELECTRICAL SERVICE REQUIREMENTS |          |              |               |
|------------------------------------------------|----------|--------------|---------------|
| EQUIPMENT TYPE                                 | QUANTITY | UNIT WATTAGE | TOTAL WATTAGE |
| SIGNAL HEAD 1 OR 3-SECTION                     | 11       | 11           | 121           |
| 4-SECTION                                      | 2        | 14           | 28            |
| 5-SECTION                                      | 4        | 13           | 52            |
| PROGRAMMABLE 3-SECTION                         | -        | 22           | -             |
| 4-SECTION                                      | -        | 32           | -             |
| 5-SECTION                                      | -        | 28           | -             |
| PEDESTRIAN SIGNAL CONTROLLER                   | 1        | 150          | 150           |
| MASTER CONTROLLER                              | -        | 100          | -             |
| UPS                                            | 1        | 25           | 25            |
| DETECTION RADAR OR VIDEO                       | -        | 20           | -             |
| BLANK-OUT SIGN                                 | -        | 25           | -             |
| NETWORK SWITCH II OR III                       | 1        | 35           | 35            |
| CELLULAR MODEM                                 | -        | 15           | -             |
| TOTAL UPS SIZING                               |          |              | 531           |
| UPS CHARGING                                   | 1        | 225          | 225           |
| BATTERY HEATER MAT                             | 1        | 180          | 180           |
| CABINET HEATER                                 | 1        | 200          | 200           |
| FLASHER                                        | -        | 15           | -             |
| LED STREET NAME SIGN                           | -        | 120          | -             |
| LUMINAIRE                                      | 4        | 240          | 960           |
| TOTAL SERVICE WIRE SIZING                      |          |              | 2096          |

|                        |                 |                |  |
|------------------------|-----------------|----------------|--|
| ENERGY COSTS TO:       |                 |                |  |
| TOWN OF CICERO         |                 |                |  |
| 4949 W CERMAK ROAD     |                 |                |  |
| CICERO, ILLINOIS 60804 |                 |                |  |
| ENERGY SUPPLY:         | CONTACT:        | ERICKA IRBY    |  |
|                        | PHONE:          | (779) 231-0633 |  |
|                        | COMPANY:        | COMED          |  |
|                        | ACCOUNT NUMBER: | 86230-10157    |  |
|                        | METER NUMBER:   | ---            |  |

|                                                   |            |           |  |
|---------------------------------------------------|------------|-----------|--|
| STATE OF ILLINOIS<br>DEPARTMENT OF TRANSPORTATION |            |           |  |
| DESIGNED -                                        | TM         | REVISED - |  |
| DRAWN -                                           | TM, SR     | REVISED - |  |
| CHECKED -                                         | JAR        | REVISED - |  |
| DATE -                                            | 05/23/2024 | REVISED - |  |

|                                      |       |           |              |
|--------------------------------------|-------|-----------|--------------|
| CABLE PLAN<br>CERMAK RD AND 49TH AVE |       |           |              |
| SCALE: NTS                           | SHEET | OF SHEETS | STA. TO STA. |

| F.A.U RTE.                | SECTION               | COUNTY      | TOTAL SHEETS | SHEET NO. |
|---------------------------|-----------------------|-------------|--------------|-----------|
| 1453                      | 2020-266-SUR, SW & TS | COOK/DUPAGE | 492          | 301       |
| CONTRACT NO. 62N39        |                       |             |              |           |
| ILLINOIS FED. AID PROJECT |                       |             |              |           |

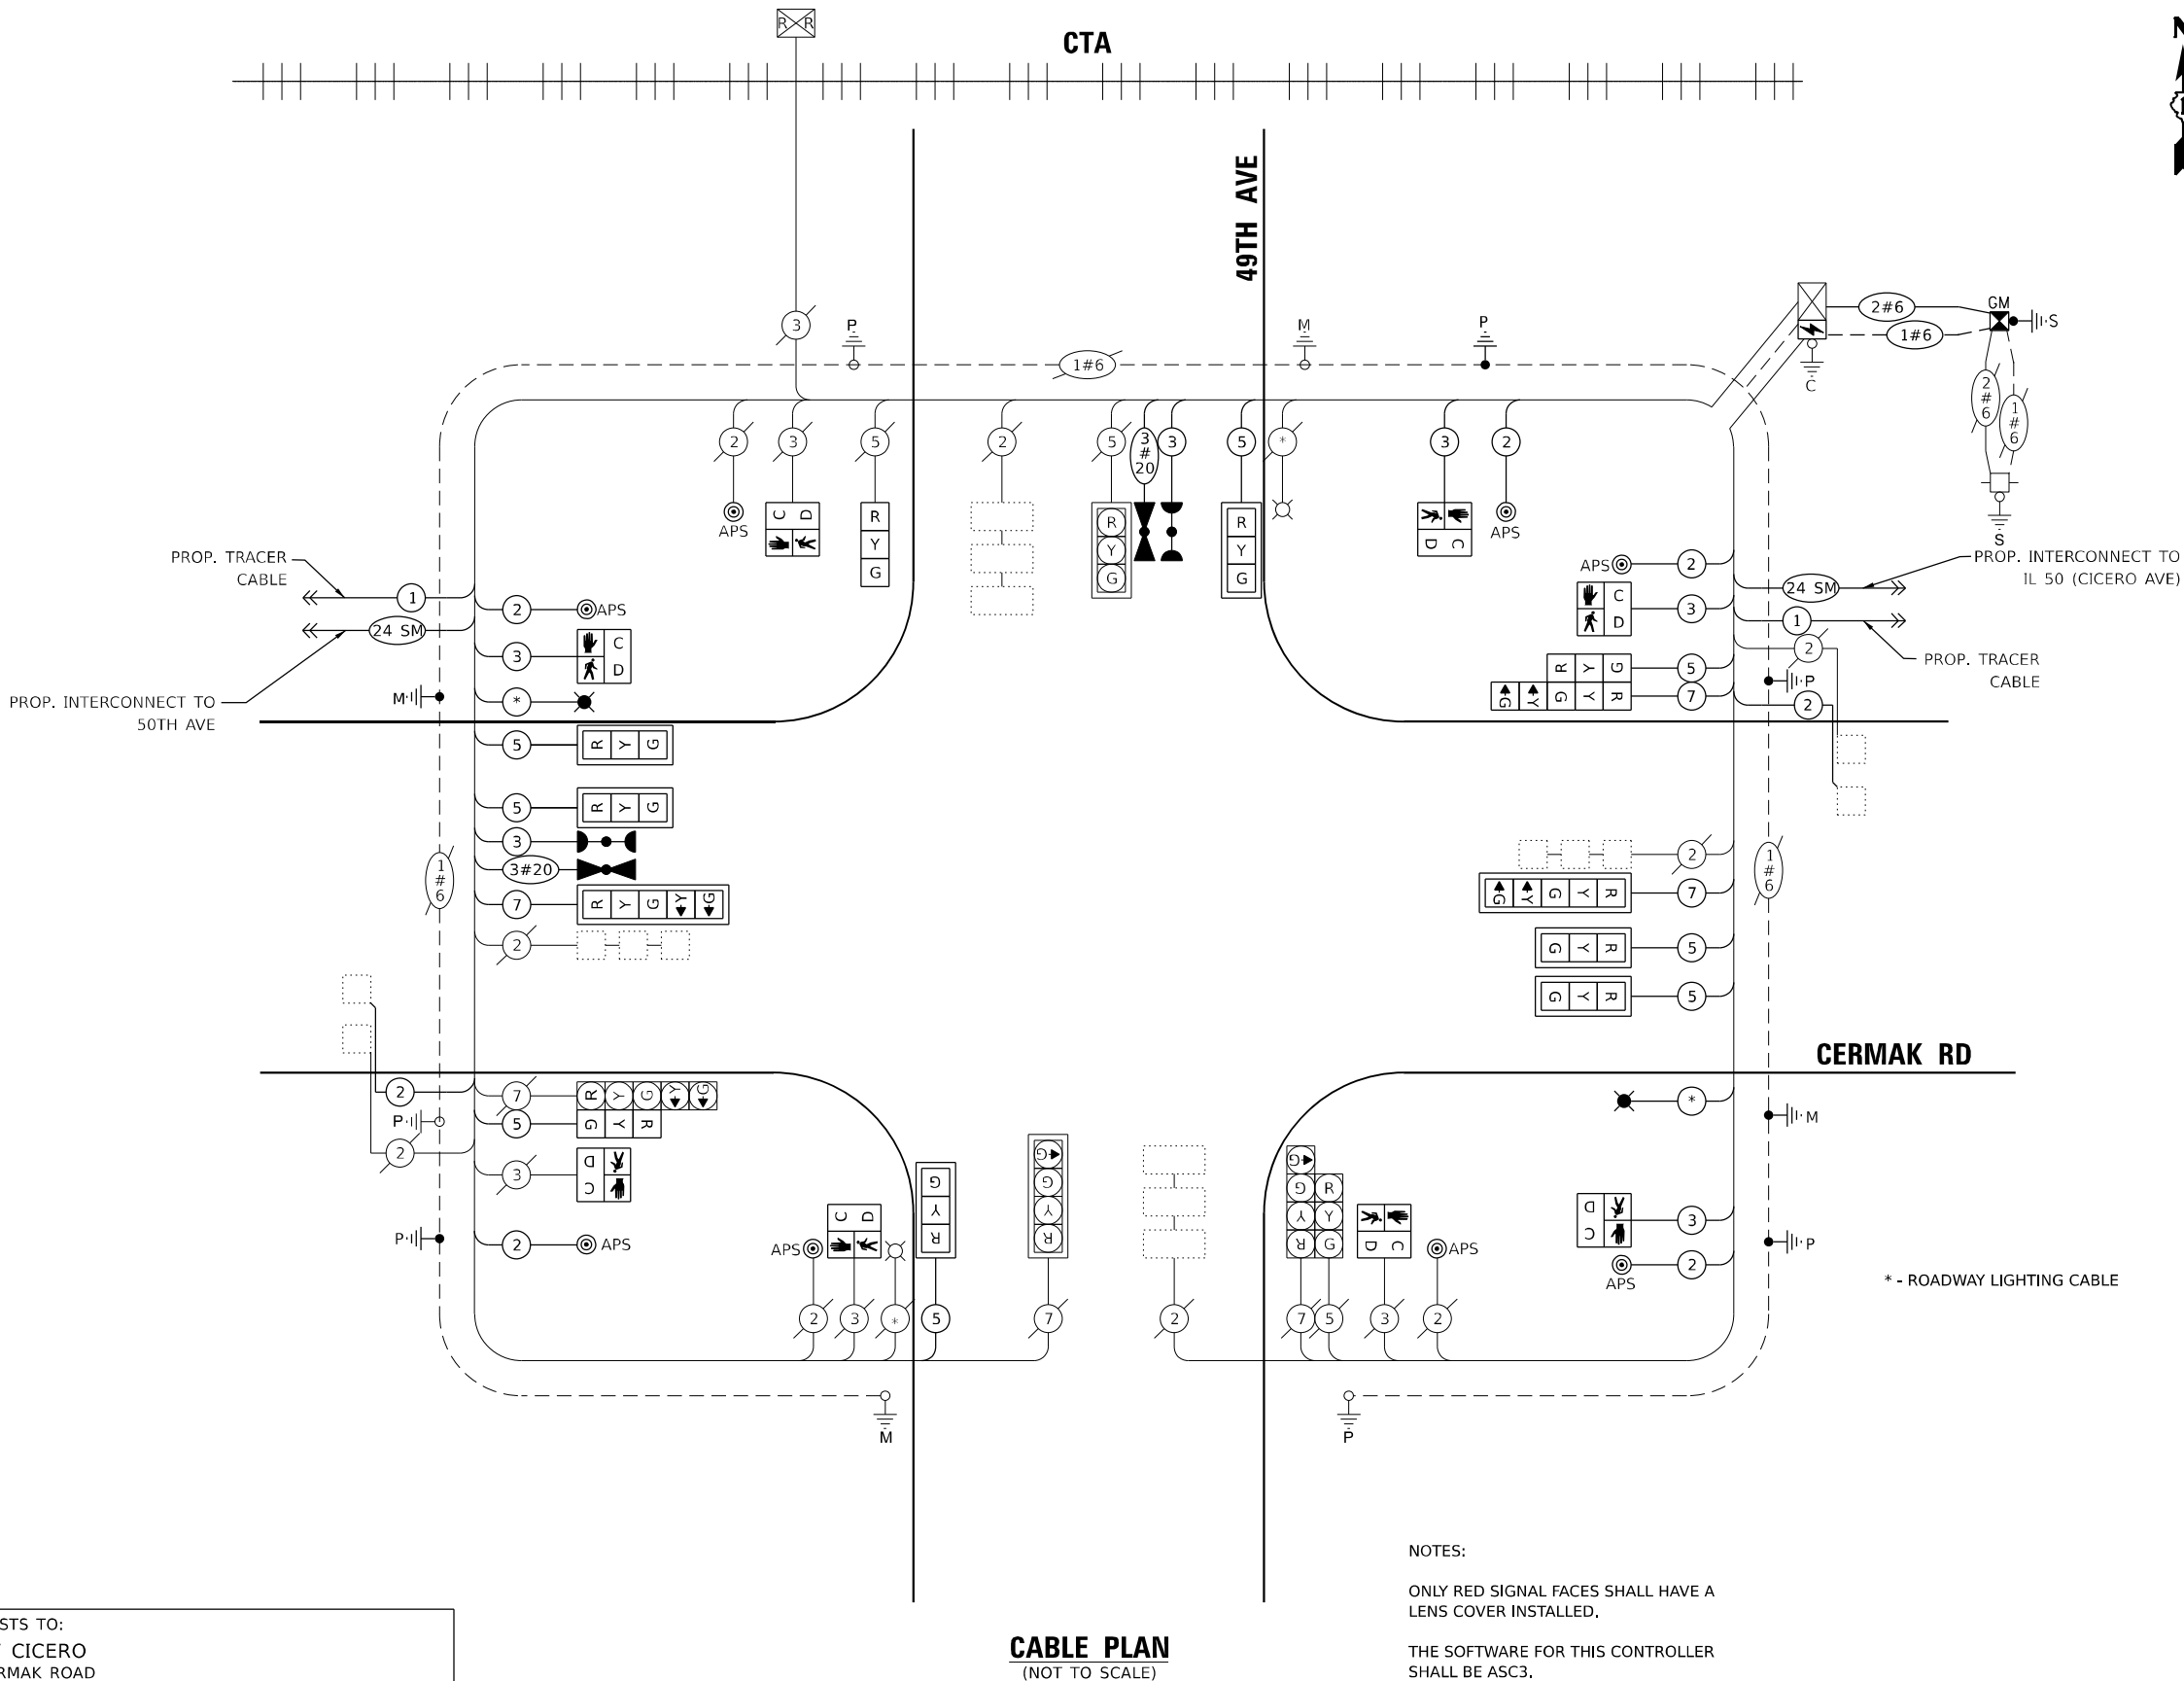

NOTES:

ONLY RED SIGNAL FACES SHALL HAVE A LENS COVER INSTALLED.

THE SOFTWARE FOR THIS CONTROLLER SHALL BE ASC3.

TS 12780  
IDOT CENTRACS  
FORMER ECON 108

### SEQUENCE OF OPERATION

| MOVEMENT                                                                |    |       |     |     |     |       |      |     |       |      |     |       |      |     |     |       |      |                          |     | F<br>L<br>A<br>S<br>H |
|-------------------------------------------------------------------------|----|-------|-----|-----|-----|-------|------|-----|-------|------|-----|-------|------|-----|-----|-------|------|--------------------------|-----|-----------------------|
| PHASE                                                                   |    | 1 + 5 |     |     |     | 1 + 6 |      |     | 2 + 5 |      |     | 2 + 6 |      |     |     | 4 + 8 |      |                          |     |                       |
| INTERVAL                                                                |    | 1     | 2   | 3   | 4   | 5     | 6    | 7   | 8     | 9    | 10  | 11    | 12   | 13A | 13B | 14    | 15   | 16A                      | 16B |                       |
| CHANGE TO PHASE                                                         |    |       | 1+6 | 2+5 | 2+6 |       |      | 2+6 |       |      | 2+6 |       |      | 4+8 |     |       |      | 1+5<br>1+6<br>2+5<br>2+6 |     |                       |
| CERMAK ROAD<br>FAR RIGHT MAST ARM SIGNAL                                | EB | R     | R   | R   | R   | R     | R    | R   | G     | G    | G   | G     | G    | Y   | R   | R     | R    | R                        | R   |                       |
| CERMAK ROAD<br>END MAST ARM AND FAR LEFT SIGNALS                        | EB |       |     |     |     | R     | R    | R   |       |      |     | G     | G    | Y   | R   | R     | R    | R                        | R   |                       |
| CERMAK ROAD<br>FAR RIGHT MAST ARM SIGNAL                                | WB | R     | R   | R   | R   | G     | G    | G   | R     | R    | R   | G     | G    | Y   | R   | R     | R    | R                        | R   |                       |
| CERMAK ROAD<br>END MAST ARM AND FAR LEFT SIGNALS                        | WB |       |     |     |     |       |      |     | R     | R    | R   | G     | G    | Y   | R   | R     | R    | R                        | R   |                       |
| 49TH AVENUE<br>ALL SIGNALS                                              | NB | R     | R   | R   | R   | R     | R    | R   | R     | R    | R   | R     | R    | R   | R   | G     | G    | Y                        | R   |                       |
| 49TH AVENUE<br>END MAST ARM AND FAR LEFT SIGNALS                        | SB | R     | R   | R   | R   | R     | R    | R   | R     | R    | R   | R     | R    | R   | R   | G     | G    | Y                        | R   |                       |
| PEDESTRIAN SIGNALS CROSSING 49TH AVENUE<br>ON NORTH SIDE OF CERMAK ROAD |    | H     | H   | H   | H   | *P    | **FH | H   | H     | H    | H   | *P    | **FH | H   | H   | H     | H    | H                        | H   |                       |
| PEDESTRIAN SIGNALS CROSSING 49TH AVENUE<br>ON SOUTH SIDE OF CERMAK ROAD |    | H     | H   | H   | H   | H     | H    | H   | *P    | **FH | H   | *P    | **FH | H   | H   | H     | H    | H                        | H   |                       |
| PEDESTRIAN SIGNALS CROSSING CERMAK ROAD<br>ON EAST SIDE OF 49TH AVENUE  |    | H     | H   | H   | H   | H     | H    | H   | H     | H    | H   | H     | H    | H   | H   | *P    | **FH | H                        | H   |                       |
| PEDESTRIAN SIGNALS CROSSING CERMAK ROAD<br>ON WEST SIDE OF 49TH AVENUE  |    | H     | H   | H   | H   | H     | H    | H   | H     | H    | H   | H     | H    | H   | H   | *P    | **FH | H                        | H   |                       |

\* TO APPEAR ONLY UPON PUSHBUTTON ACTUATION

**\*\* FLASHING "🚶" IS TO TERMINATE AT THE COMPLETION  
OF THE PEDESTRIAN INTERVAL CLEARANCE**

⊕ THIS "  " OR FLASHING "  " INTERVAL MAY FINISH TIMING IN THE BIDIRECTIONAL STRAIGHT THROUGH MOVEMENT IF THE LEFT ARROW TIME IS NOT SUFFICIENT TO COMPLETE "  " OR FLASHING "  " INTERVALS 

P = ILLUMINATED PERSON = WALK  
FH = ILLUMINATED FLASHING HAND = FLASHING DON'T WALK  
H = ILLUMINATED SOLID HAND = DON'T WALK

PHASE 2 AND 6 SHALL BE PLACED ON RECALL.

## **EMERGENCY VEHICLE PREEMPTION SEQUENCE OF OPERATION**

| EMERGENCY VEHICLE PREEMPTION SEQUENCE OF OPERATION                              |           |          |          |          |    |    |          |          |          |    |    |    |    |    |    |    |    |    |    | PREEMPTOR<br>NUMBER 3 | PREEMPTOR<br>NUMBER 4 | CLEAR<br>TO<br>NORMAL<br>SEQUENCE |
|---------------------------------------------------------------------------------|-----------|----------|----------|----------|----|----|----------|----------|----------|----|----|----|----|----|----|----|----|----|----|-----------------------|-----------------------|-----------------------------------|
| CHANGE FROM NORMAL SEQUENCE<br>OF OPERATION INTERVAL NUMBER                     | 1         | 5        |          |          | 5  |    |          | 8        |          | 8  |    |    | 11 | 11 |    |    | 14 |    |    | 14                    |                       |                                   |
| EMERGENCY VEHICLE PREEMPTION SEQUENCE<br>OF OPERATION INTERVAL NUMBER           | 1A        | 1B       | 1C       | 1D       | 1E | 1F | 1G       | 1H       | 1J       | 1K | 1L | 1M | 1N | 1P | 1Q | 1R | 1S | 1T | 1U | 2                     | 3                     |                                   |
| CHANGE TO EMERGENCY VEHICLE PREEMPTION<br>SEQUENCE OF OPERATION INTERVAL NUMBER | 2 OR<br>3 | 1C       | 2        | 1E       | 1F | 3  | 1H       | 2        | 1K       | 1L | 3  | 2  | 1P | 1Q | 3  | 1S | 1T | 2  | 3  |                       |                       | ◇                                 |
| CERMAK ROAD<br>FAR RIGHT MAST ARM SIGNAL EB                                     | R         | R        | R        | R        | R  | R  | G        | G        | G        | Y  | R  | G  | G  | Y  | R  | R  | R  | R  | R  | G                     | R                     | ◇                                 |
| CERMAK ROAD<br>END MAST ARM AND FAR LEFT SIGNALS EB                             | R<br>← Y  | R        | R        | R        | R  | R  | G<br>← G | G<br>← Y | G<br>← G | Y  | R  | G  | G  | Y  | R  | R  | R  | R  | R  | G                     | R                     | ◇                                 |
| CERMAK ROAD<br>FAR RIGHT MAST ARM SIGNAL WB                                     | R         | G        | G        | G        | Y  | R  | R        | R        | R        | R  | R  | G  | G  | Y  | R  | R  | R  | R  | R  | G                     | R                     | ◇                                 |
| CERMAK ROAD<br>END MAST ARM AND FAR LEFT SIGNALS WB                             | R<br>← Y  | G<br>← G | G<br>← Y | G<br>← G | Y  | R  | R        | R        | R        | R  | R  | G  | G  | Y  | R  | R  | R  | R  | R  | G                     | R                     | ◇                                 |
| 49TH AVENUE<br>ALL SIGNALS NB                                                   | R         | R        | R        | R        | R  | R  | R        | R        | R        | R  | R  | R  | R  | R  | R  | G  | Y  | R  | G  | R                     | G                     | ◇                                 |
| 49TH AVENUE<br>END MAST ARM AND FAR LEFT SIGNALS SB                             | R         | R        | R        | R        | R  | R  | R        | R        | R        | R  | R  | R  | R  | R  | R  | G  | Y  | R  | G  | R                     | G                     | ◇                                 |
| PEDESTRIAN SIGNALS CROSSING 49TH AVENUE<br>ON NORTH SIDE OF CERMAK ROAD         | H         | FH       | H        | FH       | H  | H  | H        | H        | H        | H  | H  | FH | FH | H  | H  | H  | H  | H  | H  | H                     | H                     | ◇                                 |
| PEDESTRIAN SIGNALS CROSSING 49TH AVENUE<br>ON SOUTH SIDE OF CERMAK ROAD         | H         | H        | H        | H        | H  | H  | FH       | H        | FH       | H  | H  | FH | FH | H  | H  | H  | H  | H  | H  | H                     | H                     | ◇                                 |
| PEDESTRIAN SIGNALS CROSSING CERMAK ROAD<br>ON EAST SIDE OF 49TH AVENUE          | H         | H        | H        | H        | H  | H  | H        | H        | H        | H  | H  | H  | H  | H  | H  | FH | H  | H  | FH | H                     | H                     | ◇                                 |
| PEDESTRIAN SIGNALS CROSSING CERMAK ROAD<br>ON WEST SIDE OF 49TH AVENUE          | H         | H        | H        | H        | H  | H  | H        | H        | H        | H  | H  | H  | H  | H  | H  | FH | H  | H  | FH | H                     | H                     | ◇                                 |

EMERGENCY VEHICLE SEQUENCE SHALL PROVIDE THE PROPER CLEARANCE INTERVAL TO RESUME THE NORMAL SEQUENCE OF OPERATION OR PROPER CLEARANCE INTERVAL TO DISPLAY A DIFFERENT EMERGENCY INTERVAL AFTER EMERGENCY VEHICLE INTERVAL 2 OR 3 IS TERMINATED.





|            |              |
|------------|--------------|
| USER NAME  | = msomer     |
| PLOT SCALE | = \$SCALE\$  |
| PLOT DATE  | = 03/19/2025 |

|            |            |
|------------|------------|
| DESIGNED - | TM         |
| DRAWN -    | TM, SR     |
| CHECKED -  | JAR        |
| DATE -     | 05/23/2024 |

|           |  |
|-----------|--|
| REVISED - |  |
| REVISED - |  |
| REVISED - |  |
| REVISED - |  |

STATE OF ILLINOIS  
DEPARTMENT OF TRANSPORTATION

|                                                                     |       |           |              |
|---------------------------------------------------------------------|-------|-----------|--------------|
| RAILROAD PREEMPTION SEQUENCE OF OPERATION<br>CERMAK RD AND 49TH AVE |       |           |              |
| SCALE: NTS                                                          | SHEET | OF SHEETS | STA. TO STA. |

|                    |                       |                  |              |           |
|--------------------|-----------------------|------------------|--------------|-----------|
| F.A.U. RTE.        | SECTION               | COUNTY           | TOTAL SHEETS | SHEET NO. |
| 1453               | 2020-266-SUR, SW & TS | COOK/DUPAGE      | 492          | 303       |
| CONTRACT NO. 62N39 |                       |                  |              |           |
| ILLINOIS           |                       | FED. AID PROJECT |              |           |

TS 12775  
IDOT CENTRACS  
FORMER ECON 108


RAILROAD PREEMPTION SEQUENCE OF OPERATION

| RAILROAD PREEMPTION SEQUENCE OF OPERATION                                         |    |         |    |    |    |    |    |    |    | PREEMPTOR<br>NUMBER 3 | PREEMPTOR<br>NUMBER 4 | PREEMPTOR<br>NUMBER 2 |    |         |   |   |   |                                   |  |
|-----------------------------------------------------------------------------------|----|---------|----|----|----|----|----|----|----|-----------------------|-----------------------|-----------------------|----|---------|---|---|---|-----------------------------------|--|
| CHANGE FROM NORMAL SEQUENCE<br>OF OPERATION INTERVAL NUMBER                       | 1  | 5       |    | 8  |    | 11 |    | 14 |    |                       |                       |                       |    |         |   |   |   |                                   |  |
| CHANGE FROM EMERGENCY VEHICLE PREEMPTION<br>SEQUENCE OF OPERATION INTERVAL NUMBER |    |         |    |    |    |    |    |    |    | 2                     |                       | 3                     |    |         |   |   |   |                                   |  |
| RAILROAD PREEMPTION SEQUENCE<br>OF OPERATION INTERVAL NUMBER                      | 1A | 1B      | 1C | 1D | 1E | 1F | 1G | 1H | 1J | 1K                    | 1L                    | 1M                    | 1N | 2       | 3 | 4 | 5 | CLEAR<br>TO<br>NORMAL<br>SEQUENCE |  |
| CHANGE TO RAILROAD PREEMPTION SEQUENCE<br>OF OPERATION INTERVAL NUMBER            | 2  | 1C      | 2  | 1E | 2  | 1G | 2  | 1J | 2  | 1L                    | 2                     | 1N                    | 2  | 3       | 4 | 5 |   |                                   |  |
| CERMAK ROAD<br>FAR RIGHT MAST ARM SIGNAL                                          | EB | R       | R  | R  | Y  | R  | Y  | R  | R  | R                     | Y                     | R                     | R  | R       | R | R | G | △                                 |  |
| CERMAK ROAD<br>END MAST ARM AND FAR LEFT SIGNALS                                  | EB | R<br>←Y | R  | R  | Y  | R  | Y  | R  | R  | R                     | Y                     | R                     | R  | R       | R | R | G | △                                 |  |
| CERMAK ROAD<br>FAR RIGHT MAST ARM SIGNAL                                          | WB | R       | Y  | R  | R  | R  | Y  | R  | R  | R                     | Y                     | R                     | R  | R       | R | R | G | △                                 |  |
| CERMAK ROAD<br>END MAST ARM AND FAR LEFT SIGNALS                                  | WB | R<br>←Y | Y  | R  | R  | R  | Y  | R  | R  | R                     | Y                     | R                     | R  | R       | R | R | G | △                                 |  |
| 49TH AVENUE<br>ALL SIGNALS                                                        | NB | R       | R  | R  | R  | R  | R  | Y  | R  | R                     | R                     | Y                     | R  | R       | R | R | R | △                                 |  |
| 49TH AVENUE<br>END MAST ARM AND FAR LEFT SIGNALS                                  | SB | R       | R  | R  | R  | R  | R  | G  | G  | R                     | R                     | G                     | G  | G<br>←G | Y | R | R | △                                 |  |
| PEDESTRIAN SIGNALS CROSSING 49TH AVENUE<br>ON NORTH SIDE OF CERMAK ROAD           |    | H       | FH | H  | H  | H  | FH | H  | H  | H                     | H                     | H                     | H  | H       | H | H | H | △                                 |  |
| PEDESTRIAN SIGNALS CROSSING 49TH AVENUE<br>ON SOUTH SIDE OF CERMAK ROAD           |    | H       | H  | H  | FH | H  | FH | H  | H  | H                     | H                     | H                     | H  | H       | H | H | H | △                                 |  |
| PEDESTRIAN SIGNALS CROSSING CERMAK ROAD<br>ON EAST SIDE OF 49TH AVENUE            |    | H       | H  | H  | H  | H  | H  | FH | H  | H                     | H                     | H                     | H  | H       | H | H | H | △                                 |  |
| PEDESTRIAN SIGNALS CROSSING CERMAK ROAD<br>ON WEST SIDE OF 49TH AVENUE            |    | H       | H  | H  | H  | H  | H  | FH | H  | H                     | H                     | H                     | H  | H       | H | H | H | △                                 |  |
|                                                                                   |    |         |    |    |    |    |    |    |    |                       |                       |                       |    |         |   |   |   | HOLD                              |  |


△ RAILROAD PREEMPTION SEQUENCE SHALL PROVIDE THE PROPER CLEARANCE  
INTERVAL TO RESUME THE NORMAL SEQUENCE OF OPERATIONS OR PROPER  
CLEARANCE INTERVAL TO DISPLAY AN EMERGENCY VEHICLE INTERVAL  
(IF APPLICABLE) AFTER RAILROAD PREEMPTION INTERVAL 5 IS TERMINATED.

SIGN PANEL – TYPE 1 OR TYPE 2

ALL DIMENSIONS ARE IN INCHES UNLESS NOTED OTHERWISE

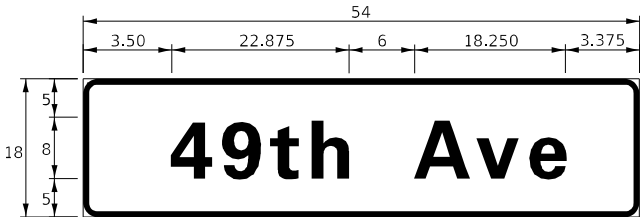

| DESIGN SERIES | AREA (SQ. FT) | SIGN PANEL TYPE | SHEETING TYPE | QTY. REQUIRED |
|---------------|---------------|-----------------|---------------|---------------|
| D             | 6.75          | 1               | ZZ            | 2             |

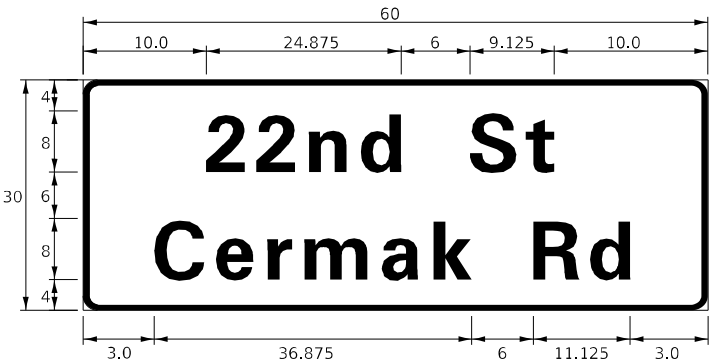

| DESIGN SERIES | AREA (SQ. FT) | SIGN PANEL TYPE | SHEETING TYPE | QTY. REQUIRED |
|---------------|---------------|-----------------|---------------|---------------|
| D             | 12.5          | 2               | ZZ            | 2             |

NOTE: FOR ADDITIONAL DESIGN AND INSTALLATION INFORMATION PLEASE SEE DISTRICT ONE MAST ARM MOUNTED STREET NAME SIGNS DETAIL.

SCHEDULE OF QUANTITIES

| ITEM DESCRIPTION                                                             | UNITS   | TOTAL QTY. |
|------------------------------------------------------------------------------|---------|------------|
| SIGN PANEL - TYPE 1                                                          | SQ. FT. | 14         |
| SIGN PANEL - TYPE 2                                                          | SQ. FT. | 25         |
| UNDERGROUND CONDUIT, GALVANIZED STEEL, 2" DIA.                               | FOOT    | 51         |
| UNDERGROUND CONDUIT, GALVANIZED STEEL, 3" DIA.                               | FOOT    | 13         |
| UNDERGROUND CONDUIT, GALVANIZED STEEL, 4" DIA.                               | FOOT    | 243        |
| HANDHOLE                                                                     | EACH    | 1          |
| LUMINAIRE, LED, ROADWAY, DESIGNATION H                                       | EACH    | 2          |
| MAINTENANCE OF EXISTING TRAFFIC SIGNAL INSTALLATION                          | EACH    | 1          |
| ELECTRIC CABLE IN CONDUIT, SIGNAL NO. 14 2C                                  | FOOT    | 782        |
| ELECTRIC CABLE IN CONDUIT, SIGNAL NO. 14 3C                                  | FOOT    | 789        |
| ELECTRIC CABLE IN CONDUIT, SIGNAL NO. 14 5C                                  | FOOT    | 1573       |
| ELECTRIC CABLE IN CONDUIT, SIGNAL NO. 14 7C                                  | FOOT    | 515        |
| ELECTRIC CABLE IN CONDUIT, LEAD-IN, NO. 14 1 PAIR                            | FOOT    | 829        |
| ELECTRIC CABLE IN CONDUIT, SERVICE, NO. 6 2C                                 | FOOT    | 40         |
| ELECTRIC CABLE IN CONDUIT, EQUIPMENT GROUNDING CONDUCTOR, NO. 6 1C           | FOOT    | 807        |
| TRAFFIC SIGNAL POST, 16 FT.                                                  | EACH    | 2          |
| STEEL COMBINATION MAST ARM ASSEMBLY AND POLE 48 FT.                          | EACH    | 1          |
| STEEL COMBINATION MAST ARM ASSEMBLY AND POLE 50 FT.                          | EACH    | 1          |
| CONCRETE FOUNDATION, TYPE A                                                  | FOOT    | 8          |
| CONCRETE FOUNDATION, TYPE E 36-INCH DIAMETER                                 | FOOT    | 28         |
| DRILL EXISTING HANDHOLE                                                      | EACH    | 6          |
| SIGNAL HEAD, LED, 1-FACE, 3-SECTION, MAST ARM MOUNTED                        | EACH    | 6          |
| SIGNAL HEAD, LED, 1-FACE, 3-SECTION, BRACKET MOUNTED                         | EACH    | 3          |
| SIGNAL HEAD, LED, 1-FACE, 5-SECTION, BRACKET MOUNTED                         | EACH    | 1          |
| SIGNAL HEAD, LED, 1-FACE, 5-SECTION, MAST ARM MOUNTED                        | EACH    | 2          |
| PEDESTRIAN SIGNAL HEAD, L.E.D., 1-FACE, BRACKET MOUNTED WITH COUNTDOWN TIMER | EACH    | 8          |
| TRAFFIC SIGNAL BACKPLATE, LOUVERED, FORMED PLASTIC                           | EACH    | 8          |
| * LIGHT DETECTOR                                                             | EACH    | 2          |
| * LIGHT DETECTOR AMPLIFIER                                                   | EACH    | 1          |
| REMOVE ELECTRIC CABLE FROM CONDUIT                                           | FOOT    | 3204       |
| REMOVE EXISTING TRAFFIC SIGNAL EQUIPMENT                                     | EACH    | 1          |
| REMOVE EXISTING CONCRETE FOUNDATION                                          | EACH    | 4          |
| * EMERGENCY VEHICLE PRIORITY SYSTEM LINE SENSOR CABLE, NO. 20 3/C            | FOOT    | 253        |
| SERVICE INSTALLATION, GROUND MOUNTED, METERED                                | EACH    | 1          |
| LAYER II (DATALINK) SWITCH                                                   | EACH    | 1          |
| UPGRADE EXISTING CONTROLLER TO NTCIP SPECIAL                                 | EACH    | 1          |
| PEDESTRIAN SIGNAL POST, 10 FT.                                               | EACH    | 2          |
| PEDESTRIAN SIGNAL POST, 5'                                                   | EACH    | 1          |
| REMOVE AND REPLACE BATTERIES FOR UNINTERRUPTABLE POWER SUPPLY, EXTENDED      | EACH    | 1          |
| ACCESSIBLE PEDESTRIAN SIGNALS                                                | EACH    | 8          |
| CONCRETE FOUNDATION, TYPE A, 12-INCH DIAMETER                                | FOOT    | 12         |
| LED SIGNAL FACE, LENS COVER                                                  | EACH    | 17         |
| CENTRACS LICENSE EXPANSION                                                   | EACH    | 1          |
| FIBER OPTIC INTERCONNECT CENTER, 48 PORT                                     | EACH    | 1          |
| LED SIGNAL MODULE REPLACEMENT                                                | EACH    | 5          |

\* - 100% COST TO TOWN OF CICERO

CONSTRUCTION NOTES:

- ① INSTALL NEW CONTROLLER IN EXISTING CABINET. THE CONTROLLER SHALL MEET RAILROAD REQUIREMENTS.
- ② INSTALL A REMOTE-CONTROLLED VIDEO SYSTEM ON THE CAMERA MOUNTING ASSEMBLY.
- ③ THE SOFTWARE FOR THIS CONTROLLER SHALL BE ASC3.
- ④ THIS INTERSECTION SHALL REMAIN ON IDOT CLOSED SYSTEM ECON 108.

ALLEY

NOTES:

- 1) THE EXISTING TRAFFIC SIGNAL EQUIPMENT SHALL NOT BE REMOVED UNTIL THE PROPOSED TRAFFIC SIGNAL EQUIPMENT IS FULLY OPERATIONAL.
- 2) ALL EXISTING TRAFFIC SIGNAL CABLE NO LONGER REQUIRED SHALL BE REMOVED.
- 3) ALL PROPOSED TRAFFIC SIGNAL CABLE SHALL BE ROUTED THROUGH THE PROPOSED CONDUIT.
- 4) A SEPARATE LEAD-IN CABLE SHALL BE INSTALLED FOR THE DETECTOR LOOPS ON THE EB CERMAK RD INSIDE THROUGH LANE AND ON THE WB CERMAK INSIDE THROUGH LANE.
- 5) THERE SHALL BE A MINIMUM OF 4' SIDEWALK CLEARANCE IN FRONT/ BEHIND OF THE TRAFFIC SIGNAL FOUNDATIONS TO BE ADA COMPLIANT.
- 6) ALL PROPOSED PUSHBUTTONS SHALL BE APS.
- 7) THIS LOCATION HAS BEEN DESIGNED TO BE ADA COMPLIANT. ANY DEVIATION FROM THIS PLAN FOR THE POSTS THAT HAVE PEDESTRIAN EQUIPMENT WILL HAVE TO BE APPROVED BY THE ENGINEER TO ENSURE ADA COMPLIANCE.

MATCH LINE A-A (SEE NEXT SHEET)

ALLEY

IL RTE 50 (CICERO AVE)

CERMAK RD

MATCH LINE B-B (SEE NEXT SHEET)

REMOVAL AND RELOCATION NOTES:

THE FOLLOWING ITEMS SHALL BE REMOVED BY THE CONTRACTOR AND SHALL BE DISPOSED OF BY THEM OUTSIDE THE RIGHT-OF-WAY AT THEIR EXPENSE. THE SALVAGE VALUE OF THE REMOVED EQUIPMENT SHALL BE REFLECTED IN THE CONTRACT BID PRICE.

- 8 EACH PEDESTRIAN SIGNAL HEAD  
6 EACH PEDESTRIAN PUSHBUTTON  
2 EACH 3-SECTION PROGRAMMABLE SIGNAL HEAD  
2 EACH 5-SECTION PROGRAMMABLE SIGNAL HEAD

THE FOLLOWING ITEMS SHALL BE REMOVED BY THE CONTRACTOR, SHALL REMAIN THE PROPERTY OF THE ILLINOIS DEPARTMENT OF TRANSPORTATION, AND SHALL BE DELIVERED BY THE CONTRACTOR TO IDOT'S TRAFFIC SIGNAL CONTRACTOR'S MAIN FACILITY.

- 1 EACH CONTROLLER (ASC/3-1000)

IDOT'S TRAFFIC SIGNAL MAINTENANCE CONTRACTOR:

MEADE ELECTRIC CO.  
6850 W 62ND ST  
CHICAGO, IL 60638  
(708) 588-2500

RAILROAD REQUIREMENTS:

PRIOR TO INSTALLATION, THE CONTRACTOR SHALL SHOP TEST THE TRAFFIC CONTROLLER AT THE EQUIPMENT VENDOR'S FACILITY WITH STAFF OF THE ICC PRESENT.

THE CONTRACTOR WILL BE RESPONSIBLE FOR COORDINATING THE REQUIRED TESTING AND INSTALLATION OF THE CONTROLLER. REPRESENTATIVES FROM IDOT, THE CONTRACTOR, THE EQUIPMENT VENDOR, AND ICC MUST BE IN ATTENDANCE FOR THE TURN-ON INSPECTION.



TS SHT NO. 156

MODEL NAME: TS156  
FILE NAME: D:\2023\TS156.MDL  
CICERO AVENUE.DGN

AMES Engineering, Inc.  
CONSULTING ENGINEERS  
6330 Belmont Road, Suite 4B  
Downers Grove, IL 60516

|            |              |
|------------|--------------|
| USER NAME  | = msomer     |
| DESIGNED   | - TM         |
| DRAWN      | - TM, SR     |
| CHECKED    | - JAR        |
| DATE       | - 05/23/2024 |
| PLOT SCALE | = \$SCALE\$  |
| PLOT DATE  | = 03/19/2025 |

|         |   |
|---------|---|
| REVISED | - |
| REVISED | - |
| REVISED | - |
| REVISED | - |

STATE OF ILLINOIS  
DEPARTMENT OF TRANSPORTATION

TRAFFIC SIGNAL MODIFICATION PLAN  
CERMAK RD AND IL RTE 50 (CICERO AVE)

SCALE: 1" = 20' SHEET OF SHEETS STA. TO STA.

| F.A.U. RTE. | SECTION               | COUNTY      | TOTAL SHEETS | SHEET NO.                 |
|-------------|-----------------------|-------------|--------------|---------------------------|
| 1453        | 2020-266-SUR, SW & TS | COOK/DUPAGE | 492          | 305                       |
|             |                       |             |              | CONTRACT NO. 62N39        |
|             |                       |             |              | ILLINOIS FED. AID PROJECT |

TS 12770  
IDOT CENTRACS  
ECON 108



|            |              |          |              |         |   |
|------------|--------------|----------|--------------|---------|---|
| USER NAME  | = msomer     | DESIGNED | - TM         | REVISED | - |
|            |              | DRAWN    | - TM, SR     | REVISED | - |
| PLOT SCALE | = \$SCALE\$  | CHECKED  | - JAR        | REVISED | - |
| PLOT DATE  | = 03/19/2025 | DATE     | - 05/23/2024 | REVISED | - |

STATE OF ILLINOIS  
DEPARTMENT OF TRANSPORTATION

TRAFFIC SIGNAL MODIFICATION PLAN (SHEET 2 OF 2)  
CERMAK ROAD AND IL RTE 50 (CICERO AVE)

SCALE: 1" = 20' SHEET OF SHEETS STA. TO STA.

| F.A.U. RTE.        | SECTION               | COUNTY      | TOTAL SHEETS     | SHEET NO. |
|--------------------|-----------------------|-------------|------------------|-----------|
| 1453               | 2020-266-SUR, SW & TS | COOK/DUPAGE | 492              | 306       |
| CONTRACT NO. 62N39 |                       |             |                  |           |
|                    |                       | ILLINOIS    | FED. AID PROJECT |           |

TS 12770  
IDOT CENTRACS  
ECON 108

IL RTE 50 (CICERO AVE)

MATCH LINE B-B (SEE PREVIOUS SHEET)

EXIST. R.O.W.

EXIST. R.O.W.

261'-E-2"

11' 11' 11' 11' 11'

EXIST. INTERCONNECT TO  
23RD STREET

EXIST. INTERCONNECT TO  
19TH STREET

IL RTE 50 (CICERO AVE)

21ST PL

80'-E-2"

15'-E-2½"

EX. 28' MAST ARM

68'-E-2½"

EX. 14' POST

6'-E-2½"

CTA

60'-E-5"

MATCH LINE A-A (SEE PREVIOUS SHEET)




| TRAFFIC SIGNAL ELECTRICAL SERVICE REQUIREMENTS |          |              |               |
|------------------------------------------------|----------|--------------|---------------|
| EQUIPMENT TYPE                                 | QUANTITY | UNIT WATTAGE | TOTAL WATTAGE |
| SIGNAL HEAD 1 OR 3-SECTION                     | 16       | 11           | 176           |
| 4-SECTION                                      | -        | 14           | -             |
| 5-SECTION                                      | 8        | 13           | 104           |
| PROGRAMMABLE 3-SECTION                         | -        | 22           | -             |
| 4-SECTION                                      | -        | 32           | -             |
| 5-SECTION                                      | -        | 28           | -             |
| PEDESTRIAN SIGNAL                              | 8        | 15           | 120           |
| CONTROLLER                                     | 1        | 150          | 150           |
| MASTER CONTROLLER                              | 1        | 100          | 100           |
| UPS                                            | 1        | 25           | 25            |
| DETECTION RADAR OR VIDEO                       | -        | 20           | -             |
| BLANK-OUT SIGN                                 | -        | 25           | -             |
| NETWORK SWITCH II OR III                       | 1        | 35           | 35            |
| PTZ CAMERA                                     | 1        | 75           | 75            |
| TOTAL UPS SIZING                               |          |              | 785           |
| UPS CHARGING                                   | 1        | 225          | 225           |
| BATTERY HEATER MAT                             | 1        | 180          | 180           |
| CABINET HEATER                                 | 1        | 200          | 200           |
| FLASHER                                        | -        | 15           | -             |
| LED STREET NAME SIGN                           | -        | 120          | -             |
| LUMINAIRE                                      | -        | 240          | -             |
| TOTAL SERVICE WIRE SIZING                      |          |              | 1390          |

|                        |                       |
|------------------------|-----------------------|
| ENERGY COSTS TO:       |                       |
| TOWN OF CICERO         |                       |
| 4949 W CERMAK ROAD     |                       |
| CICERO, ILLINOIS 60804 |                       |
| ENERGY SUPPLY:         | CONTACT: ERICKA IRBY  |
|                        | PHONE: (779) 231-0633 |
|                        | COMPANY: COMED        |
| ACCOUNT NUMBER:        | 86230-10157           |
| METER NUMBER:          | ---                   |

STATE OF ILLINOIS  
DEPARTMENT OF TRANSPORTATION

CABLE PLAN  
CERMAK RD AND IL RTE 50 (CICERO AVE)

| F.A.U RTE.                | SECTION               | COUNTY      | TOTAL SHEETS | SHEET NO. |
|---------------------------|-----------------------|-------------|--------------|-----------|
| 1453                      | 2020-266-SUR, SW & TS | COOK/DUPAGE | 492          | 307       |
| CONTRACT NO. 62N39        |                       |             |              |           |
| ILLINOIS FED. AID PROJECT |                       |             |              |           |

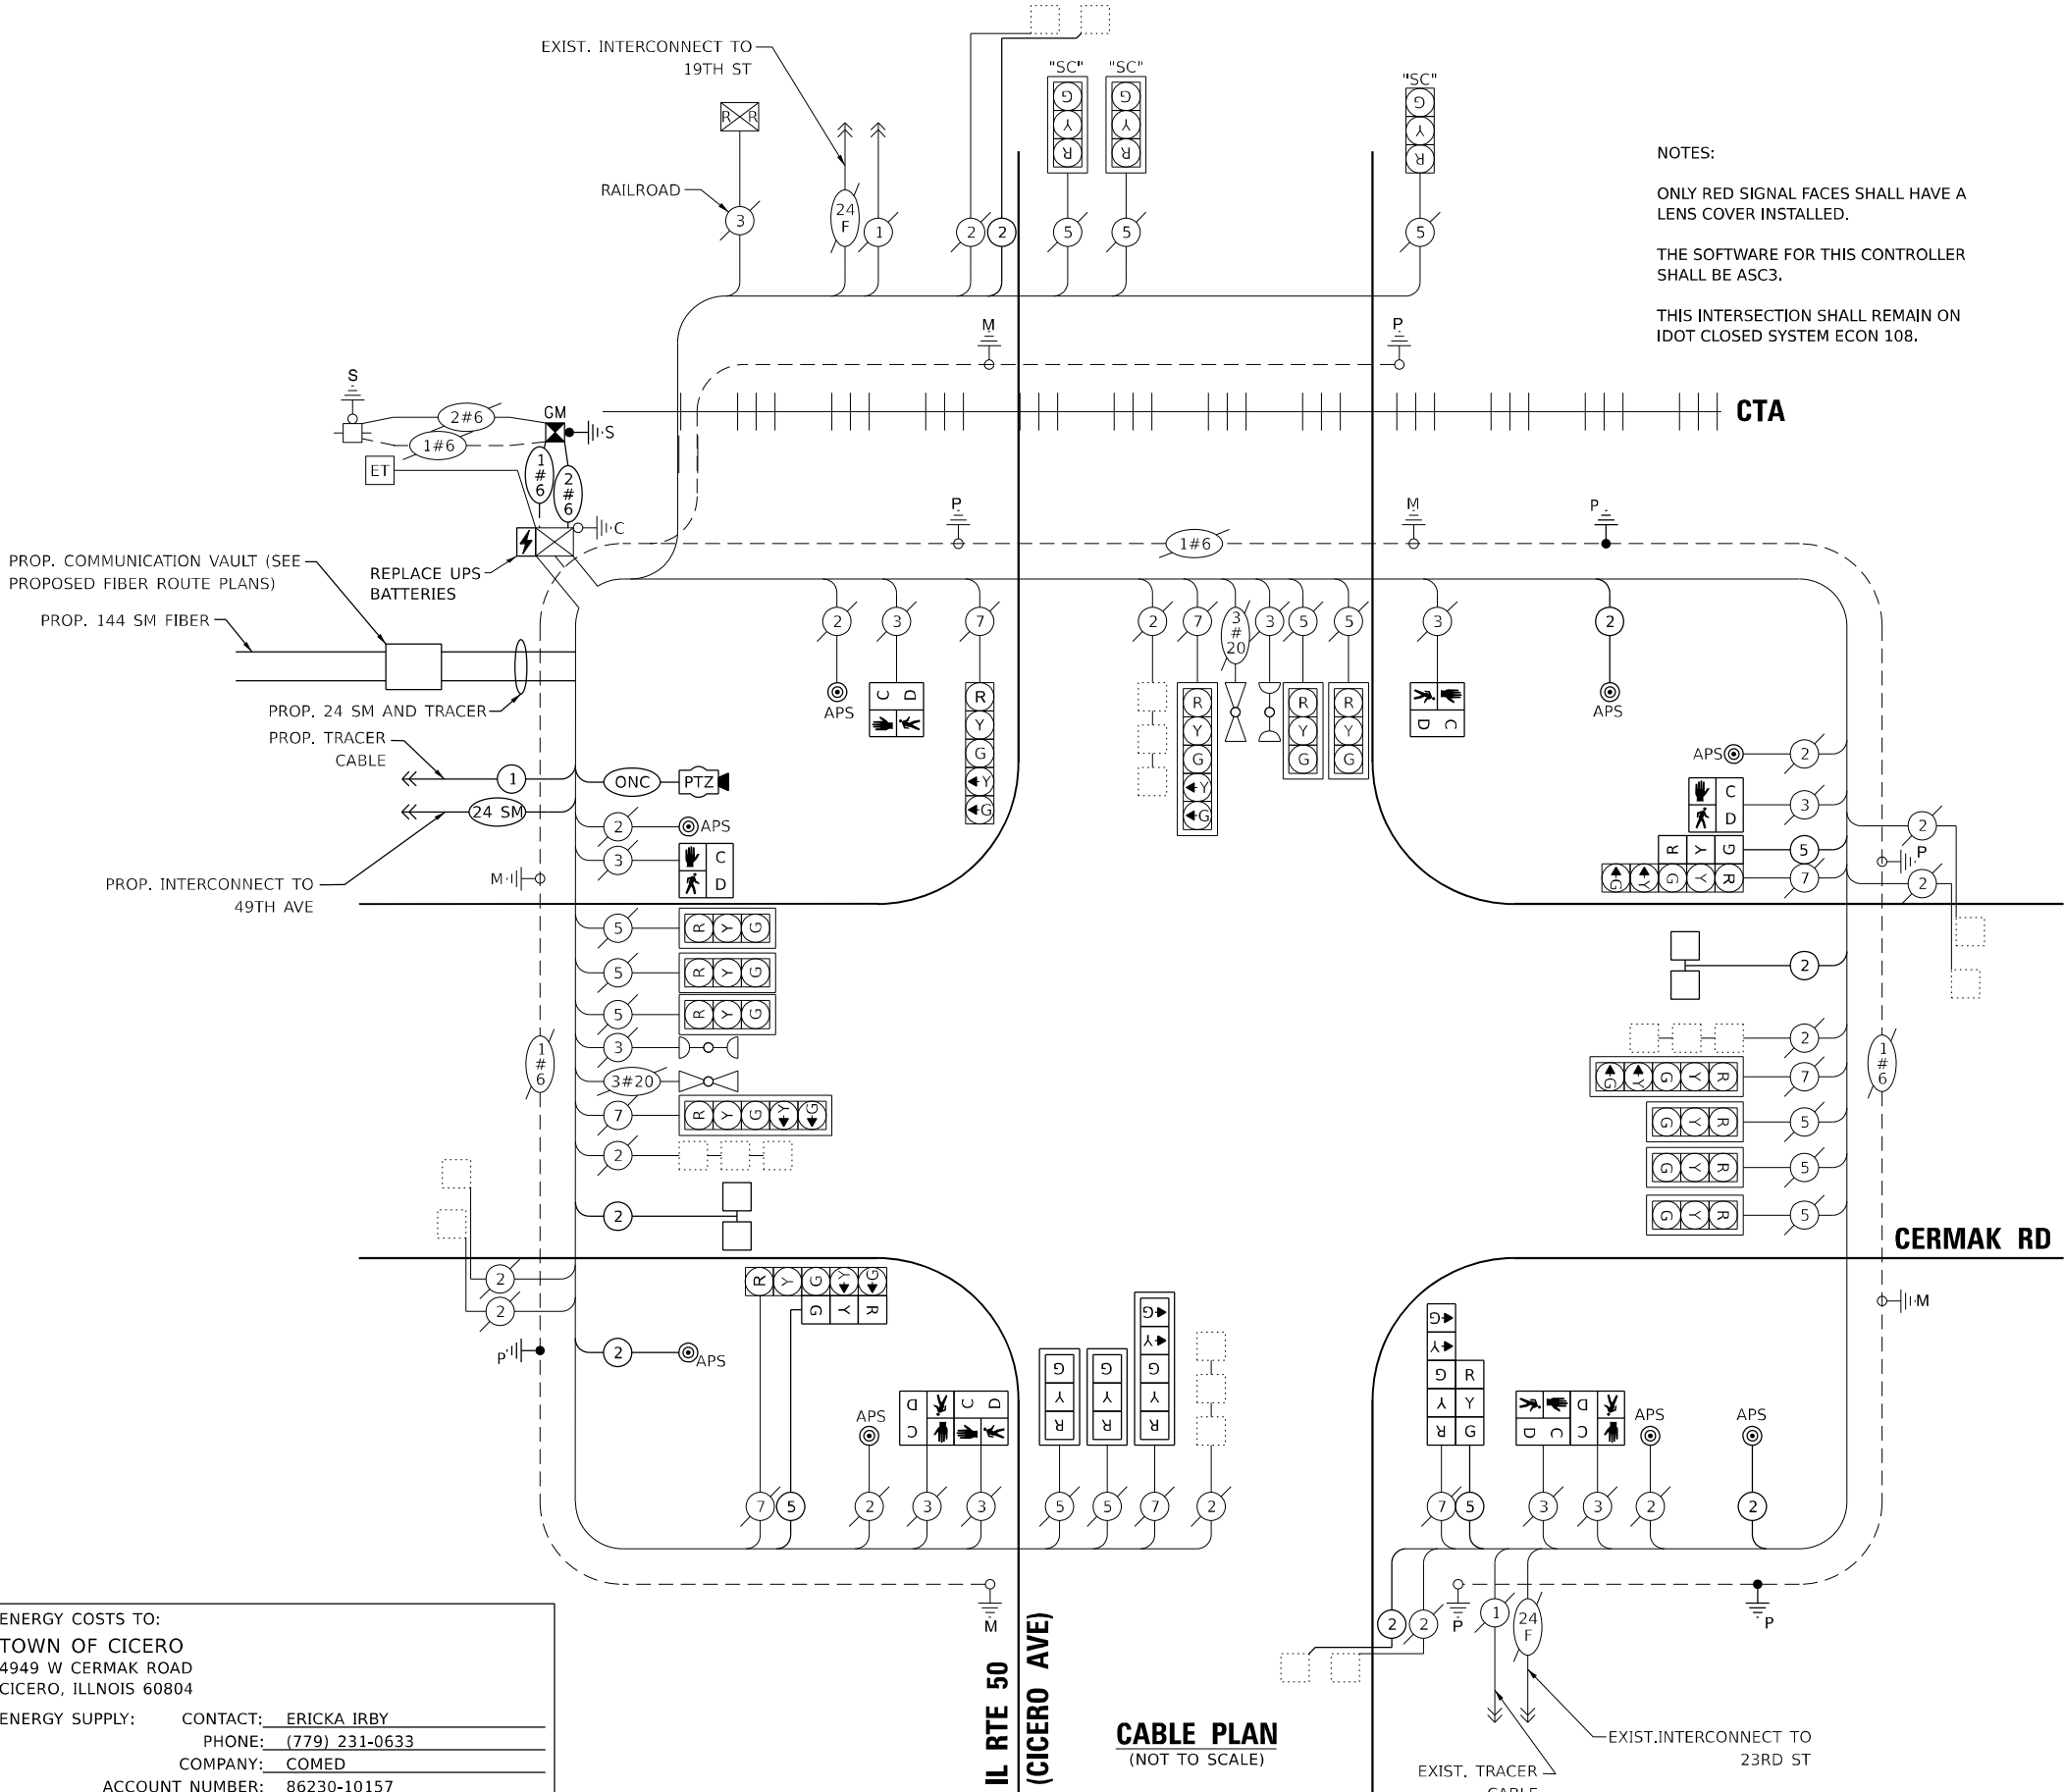

TS 12770  
IDOT CENTRACS  
ECON 108

| MOVEMENT                                                                        | <br>1<br>5 | |F L A S H |
|---|
| PHASE                                                                           | 1 + 5      |     |     |     |     |     | 1 + 6 |      |     | 2 + 5 |      |     | 2 + 6 |      |                          |     |     |     |     | 3 + 7 |     |                                 |     | 3 + 8 |                          |     |     |     |                          |     |     | 4 + 7 |                          |      |     |     | 4 + 8 |   |   |  |           |
| INTERVAL                                                                        | 1          | 2   | 3   | 4A  | 4B  | 4C  | 5     | 6    | 7   | 8     | 9    | 10  | 11    | 12   | 13A                      | 13B | 13C | 13D | 14  | 15    | 16  | 17                              | 18  | 19    | 20A                      | 20B | 21  | 22  | 23                       | 24A | 24B | 25    | 26                       | 27   | 28A | 28B |       |   |   |  |           |
| CHANGE TO PHASE                                                                 | /          | 1+6 | 2+5 | 2+6 |     |     | /     | /    | 2+6 | /     | /    | 2+6 | /     | /    | 3+7<br>3+8<br>4+7<br>4+8 |     |     |     | /   | 3+8   | 4+7 | 1+5<br>1+6<br>2+5<br>2+6<br>4+8 | /   | /     | 1+5<br>1+6<br>2+5<br>2+6 | 4+8 | /   | /   | 1+5<br>1+6<br>2+5<br>2+6 | 4+8 | /   | /     | 1+5<br>1+6<br>2+5<br>2+6 |      |     |     |       |   |   |  |           |
| IL 50 (CICERO AVE.)<br>FAR RIGHT AND MID MAST ARM SIGNALS                       | NB         | R   | R   | R   | R   | R   | R     | R    | R   | G     | G    | G   | G     | G    | G                        | G   | Y   | R   | R   | R     | R   | R                               | R   | R     | R                        | R   | R   | R   | R                        | R   | R   | R     | R                        | R    | R   | R   | R     |   |   |  |           |
| IL 50 (CICERO AVE.)<br>END MAST ARM AND FAR LEFT SIGNALS                        | NB         | L←G | L←Y | L←G | L←Y |     | R     | R    | R   | L←G   | L←G  | L←Y | G     | G    | G                        | G   | Y   | R   | R   | R     | R   | R                               | R   | R     | R                        | R   | R   | R   | R                        | R   | R   | R     | R                        | R    | R   | R   | R     |   |   |  |           |
| IL 50 (CICERO AVE.) - (NORTH OF TRACKS)<br>ALL SIGNALS                          | SB         | R   | R   | R   | R   | R   | G     | G    | G   | R     | R    | R   | G     | G    | Y                        | R   | R   |   |  |           |
| IL 50 (CICERO AVE.) - (SOUTH OF TRACKS)<br>FAR RIGHT AND MID MAST ARM SIGNALS   | SB         | R   | R   | R   | R   | R   | G     | G    | G   | R     | R    | R   | G     | G    | G                        | G   | Y   | R   | R   |   |  |           |
| IL 50 (CICERO AVE.) - (SOUTH OF TRACKS)<br>END MAST ARM AND FAR LEFT SIGNALS    | SB         | L←G | L←G | L←Y | L←G | L←G | L←Y   | L←G  | L←G | L←Y   | R    | R   | G     | G    | G                        | G   | Y   | R   | R   |   |  |           |
| CERMAK ROAD - FAR RIGHT,<br>MID RIGHT AND MID LEFT MAST ARM SIGNALS             | EB         | R   | R   | G   | G                        | Y   | R   | G     | G                        | G    | Y   | R   | R     | R |   |  |           |
| CERMAK ROAD<br>END MAST ARM AND FAR LEFT SIGNALS                                | EB         | R   | R   | R   | R   | R   | R     | R    | R   | R     | R    | R   | R     | R    | R                        | R   | R   | R   | L←G | L←Y   | L←G | L←Y                             | R   | R     | R                        | R   | R   | L←G | L←G                      | Y   | R   | L←Y   | G                        | G    | Y   | R   | R     | R |   |  |           |
| CERMAK ROAD - FAR RIGHT,<br>MID RIGHT AND MID LEFT MAST ARM SIGNALS             | WB         | R   | R   | G   | G     | Y                        | R   | G   | R   | R                        | R   | R   | R     | R                        | G    | G   | Y   | R     | R | R |  |           |
| CERMAK ROAD<br>END MAST ARM AND FAR LEFT SIGNALS                                | WB         | R   | R   | R   | R   | R   | R     | R    | R   | R     | R    | R   | R     | R    | R                        | R   | R   | R   | L←G | L←G   | L←Y | L←Y                             | L←G | L←G   | Y                        | R   | L←Y | R   | R                        | R   | R   | R     | G                        | G    | Y   | R   | R     | R | R |  |           |
| PEDESTRIAN SIGNALS CROSSING CERMAK ROAD<br>ON EAST SIDE OF IL 50 (CICERO AVE.)  |            | H   | H   | H   | H   | H   | H     | H    | H   | *P    | **FH | H   | *P    | **FH | H                        | H   |  |           |
| PEDESTRIAN SIGNALS CROSSING CERMAK ROAD<br>ON WEST SIDE OF IL 50 (CICERO AVE.)  |            | H   | H   | H   | H   | H   | *P    | **FH | H   | H     | H    | H   | *P    | **FH | H                        | H   |  |           |
| PEDESTRIAN SIGNALS CROSSING IL 50 (CICERO<br>AVE.) ON NORTH SIDE OF CERMAK ROAD |            | H   | H   | *P  | **FH  | H                        | H   | H   | H   | H                        | H   | H   | H     | *P                       | **FH | H   | H   | H     | H | H |  |           |
| PEDESTRIAN SIGNALS CROSSING IL 50 (CICERO<br>AVE.) ON SOUTH SIDE OF CERMAK ROAD |            | H   | H   | *P  | **FH                     | H   | H   | H     | *P                       | **FH | H   | H   | H     | H | H |  |           |

P = ILLUMINATED PERSON = WALK  
FH = ILLUMINATED FLASHING HAND = FLASHING DON'T WALK  
H = ILLUMINATED SOLID HAND = DON'T WALK

EMERGENCY VEHICLE SEQUENCE SHALL PROVIDE THE PROPER CLEARANCE INTERVAL TO RESUME THE NORMAL SEQUENCE OF OPERATION OR PROPER CLEARANCE INTERVAL TO DISPLAY A DIFFERENT EMERGENCY INTERVAL AFTER EMERGENCY VEHICLE INTERVAL 2 OR 3 IS TERMINATED.

|                                                                               | 1     | 1     |       |       | 5     |       |       | 5     |       |       |    |    |       | 8     |       | 8  |    |    | 11 | 11 |    |    |                     |       |     | 14  | 18    |       |     | 18    |     | 22  |       |       | 22  |     | 22  |   |    | 22 |   |  | CLEAR TO NORMAL SEQUENCE |
|---|
| CHANGE FROM NORMAL SEQUENCE OF OPERATION INTERVAL NUMBER                      | 1A    | 1B    | 1C    | 1D    | 1E    | 1F    | 1G    | 1H    | 1J    | 1K    | 1L | 1M | 1N    | 1P    | 1Q    | 1R | 1S | 1T | 1U | 1V | 1W | 1X | 1Y                  | 1Z    | 1AA | 1BB | 1CC   | 1DD   | 1EE | 1FF   | 1GG | 1HH | 1JJ   | 1KK   | 1LL | 1MM | 1NN |   | 2  | 3  |   |  |                          |
| EMERGENCY VEHICLE PREEMPTION SEQUENCE OF OPERATION INTERVAL NUMBER            | 2     | 1C    | 1D    | 3     | 1F    | 1G    | 2     | 1H    | 1J    | 1K    | 1L | 3  | 1N    | 2     | 1Q    | 1R | 3  | 2  | 1U | 1V | 1W | 1X | 3 <sup>2 OR 3</sup> | 1AA   | 1BB | 2   | 1DD   | 3     | 1FF | 1GG   | 2   | 1JJ | 3     | 1LL   | 1MM | 2   | 3   |   |    |    |   |  |                          |
| IL 50 (CICERO AVE.) FAR RIGHT AND MID MAST ARM SIGNALS NB                     | R     | R     | R     | R     | R     | R     | R     | R     | R     | R     | R  | R  | G     | G     | G     | Y  | R  | G  | G  | G  | G  | Y  | R                   | R     | R   | R   | R     | R     | R   | R     | R   | R   | R     | R     | R   | R   | R   | R | R  | G  | R |  |                          |
| IL 50 (CICERO AVE.) END MAST ARM AND FAR LEFT SIGNALS NB                      | R ← Y | R ← Y | R     | R     | R     | R     | R     | R     | R     | R     | R  | R  | G ← G | G ← Y | G ← G | Y  | R  | G  | G  | G  | G  | Y  | R                   | R     | R   | R   | R     | R     | R   | R     | R   | R   | R     | R     | R   | R   | R   | R | G  | R  |   |  |                          |
| IL 50 (CICERO AVE.) - (NORTH OF TRACKS) ALL SIGNALS SB                        | R     | R     | R     | R     | G     | G     | G     | G     | Y     | R     | R  | R  | R     | R     | R     | R  | G  | G  | Y  | R  | R  | R  | R                   | R     | R   | R   | R     | R     | R   | R     | R   | R   | R     | R     | R   | R   | R   | R | G  | R  |   |  |                          |
| IL 50 (CICERO AVE.) - (SOUTH OF TRACKS) FAR RIGHT AND MID MAST ARM SIGNALS SB | R     | R     | R     | R     | G     | G     | G     | G     | G     | Y     | R  | R  | R     | R     | R     | R  | G  | G  | G  | G  | Y  | R  | R                   | R     | R   | R   | R     | R     | R   | R     | R   | R   | R     | R     | R   | R   | R   | R | G  | R  |   |  |                          |
| IL 50 (CICERO AVE.) - (SOUTH OF TRACKS) END MAST ARM AND FAR LEFT SIGNALS SB  | R ← Y | R ← G | R ← G | R ← Y | G ← G | G ← G | G ← Y | G ← G | G ← G | G ← G | Y  | R  | R     | R     | R     | R  | G  | G  | G  | G  | Y  | R  | R                   | R     | R   | R   | R     | R     | R   | R     | R   | R   | R     | R     | R   | R   | R   | G | R  |    |   |  |                          |
| CERMAK ROAD - FAR RIGHT, MID RIGHT AND MID LEFT MAST ARM SIGNALS EB           | R     | R     | G     | Y   | R   | G     | G     | G   | Y   | R   | G | R  | G  |   |  |                          |
| CERMAK ROAD END MAST ARM AND FAR LEFT SIGNALS EB                              | R     | R     ← Y               | R     | R   | R   | R     | R     | R   | G ← G | Y   | R   | G ← G | G ← Y | G   | Y   | R   | G | R  | G  |   |  |                          |
| CERMAK ROAD - FAR RIGHT, MID RIGHT AND MID LEFT MAST ARM SIGNALS WB           | R     | R     | G   | Y   | R     | G     | G   | R     | R   | R   | R     | R     | G   | Y   | R   | G | R  | G  |   |  |                          |
| CERMAK ROAD END MAST ARM AND FAR LEFT SIGNALS WB                              | R     | R     ← Y               | G ← G | Y   | R   | G ← G | G ← Y | R   | R     | R   | R   | R     | G     | Y   | R   | G   | R | G  | R  | G |  |                          |
| PEDESTRIAN SIGNALS CROSSING CERMAK ROAD ON EAST SIDE OF IL 50 (CICERO AVE.)   | H     | H     | H     | H     | H     | H     | H     | H     | H     | H     | H  | H  | FH    | H     | FH    | H  | H  | FH | FH | H  | H  |  |                          |
| PEDESTRIAN SIGNALS CROSSING CERMAK ROAD ON WEST SIDE OF IL 50 (CICERO AVE.)   | H     | H     | H     | H     | FH    | H     | H     | FH    | H     | H     | H  | H  | H     | H     | H     | H  | FH | FH | H  | H  |  |                          |
| PEDESTRIAN SIGNALS CROSSING IL 50 (CICERO AVE.) ON NORTH SIDE OF CERMAK ROAD  | H     | H     | H     | H     | H     | H     | H     | H     | H     | H     | H  | H  | H     | H     | H     | H  | FH | H  | H  | FH | H  | H  | H                   | H     | FH  | H   | H     | FH    | H   | H     | H   | H   | H     | FH    | H   | H   | FH  | H | H  | H  | H |  |                          |
| PEDESTRIAN SIGNALS CROSSING IL 50 (CICERO AVE.) ON SOUTH SIDE OF CERMAK ROAD  | H     | H     | H     | H     | H     | H     | H     | H     | H     | H     | H  | H  | H     | H     | H     | H  | FH | H  | H  | FH | H  | H  | H                   | H     | H   | H   | H     | H     | H   | FH    | H   | H   | FH    | H     | H   | FH  | H   | H | FH | H  | H |  |                          |



MODEL: 160 PRELIMINARY  
FILE NAME: D:\2023\23-24\TS160 SE02 Cicero Avenue.dgn



|            |              |
|------------|--------------|
| USER NAME  | = msomer     |
| PLOT SCALE | = \$SCALE\$  |
| PLOT DATE  | = 03/19/2025 |

|          |   |            |
|----------|---|------------|
| DESIGNED | - | TM         |
| DRAWN    | - | TM, SR     |
| CHECKED  | - | JAR        |
| DATE     | - | 05/23/2024 |

|         |   |
|---------|---|
| REVISED | - |
| REVISED | - |
| REVISED | - |
| REVISED | - |

STATE OF ILLINOIS  
DEPARTMENT OF TRANSPORTATION

|                                                                                   |       |           |              |
|-----------------------------------------------------------------------------------|-------|-----------|--------------|
| RAILROAD PREEMPTION SEQUENCE OF OPERATION<br>CERMAK RD AND IL RTE 50 (CICERO AVE) |       |           |              |
| SCALE: NTS                                                                        | SHEET | OF SHEETS | STA. TO STA. |

|                    |                       |             |                  |           |
|--------------------|-----------------------|-------------|------------------|-----------|
| F.A.U RTE.         | SECTION               | COUNTY      | TOTAL SHEETS     | SHEET NO. |
| 1453               | 2020-266-SUR, SW & TS | COOK/DUPAGE | 492              | 309       |
| CONTRACT NO. 62N39 |                       |             |                  |           |
|                    |                       | ILLINOIS    | FED. AID PROJECT |           |

TS 12770  
IDOT CENTRACS  
ECON 108

| RAILROAD PREEMPTION SEQUENCE OF OPERATION                                         |    |         |         |         |    |    |    |         |    |    |    |    |    |    |    | PREEMPTOR<br>NUMBER 3 | PREEMPTOR<br>NUMBER 4 | PREEMPTOR<br>NUMBER 2 |         |   |   |   |                                   |  |  |  |  |
|-----------------------------------------------------------------------------------|----|---------|---------|---------|----|----|----|---------|----|----|----|----|----|----|----|-----------------------|-----------------------|-----------------------|---------|---|---|---|-----------------------------------|--|--|--|--|
| CHANGE FROM NORMAL SEQUENCE<br>OF OPERATION INTERVAL NUMBER                       | 1  | 5       |         |         | 8  |    |    | 11      |    |    | 14 | 18 |    |    | 22 |                       |                       | 26                    |         |   |   |   |                                   |  |  |  |  |
| CHANGE FROM EMERGENCY VEHICLE PREEMPTION<br>SEQUENCE OF OPERATION INTERVAL NUMBER |    |         |         |         |    |    |    |         |    |    |    |    |    |    |    | 2                     |                       | 3                     |         |   |   |   |                                   |  |  |  |  |
| RAILROAD PREEMPTION SEQUENCE<br>OF OPERATION INTERVAL NUMBER                      | 1A | 1B      | 1C      | 1D      | 1E | 1F | 1G | 1H      | 1J | 1K | 1L | 1M | 1N | 1P | 1Q | 1R                    | 1S                    | 1T                    | 2       | 3 | 4 | 5 | CLEAR<br>TO<br>NORMAL<br>SEQUENCE |  |  |  |  |
| CHANGE TO RAILROAD PREEMPTION SEQUENCE<br>OF OPERATION INTERVAL NUMBER            | 2  | 1C      | 2       | 1E      | 2  | 1G | 2  | 2       | 1K | 2  | 1M | 2  | 1P | 2  | 1R | 2                     | 1T                    | 2                     | 3       | 4 | 5 |   |                                   |  |  |  |  |
| IL 50 (CICERO AVE.)<br>FAR RIGHT AND MID MAST ARM SIGNALS                         | NB | R       | R       | R       | Y  | R  | Y  | R       | R  | R  | R  | R  | R  | R  | Y  | R                     | R                     | R                     | R       | R | R | R | △                                 |  |  |  |  |
| IL 50 (CICERO AVE.)<br>END MAST ARM AND FAR LEFT SIGNALS                          | NB | R<br>←Y | R       | R       | Y  | R  | Y  | R       | R  | R  | R  | R  | R  | R  | Y  | R                     | R                     | R                     | R       | R | R | R | △                                 |  |  |  |  |
| IL 50 (CICERO AVE.) - (NORTH OF TRACKS)<br>ALL SIGNALS                            | SB | R       | Y       | R       | R  | R  | Y  | R       | R  | R  | R  | R  | R  | R  | Y  | R                     | R                     | R                     | R       | R | R | R | △                                 |  |  |  |  |
| IL 50 (CICERO AVE.) - (SOUTH OF TRACKS)<br>FAR RIGHT AND MID MAST ARM SIGNALS     | SB | R       | G       | G       | R  | R  | G  | G       | R  | R  | R  | R  | R  | R  | G  | G                     | R                     | R                     | G       | Y | R | R | △                                 |  |  |  |  |
| IL 50 (CICERO AVE.) - (SOUTH OF TRACKS)<br>END MAST ARM AND FAR LEFT SIGNALS      | SB | R<br>←G | G<br>←G | G<br>←G | R  | R  | G  | G       | R  | R  | R  | R  | R  | R  | G  | G                     | R                     | R                     | G<br>←G | Y | R | R | △                                 |  |  |  |  |
| CERMAK ROAD - FAR RIGHT,<br>MID RIGHT AND MID LEFT MAST ARM SIGNALS               | EB | R       | R       | R       | R  | R  | R  | R       | R  | R  | Y  | R  | Y  | R  | R  | R                     | Y                     | R                     | R       | R | R | G | △                                 |  |  |  |  |
| CERMAK ROAD<br>END MAST ARM AND FAR LEFT SIGNALS                                  | EB | R       | R       | R       | R  | R  | R  | R<br>←Y | R  | R  | Y  | R  | Y  | R  | R  | R                     | Y                     | R                     | R       | R | G | △ |                                   |  |  |  |  |
| CERMAK ROAD - FAR RIGHT,<br>MID RIGHT AND MID LEFT MAST ARM SIGNALS               | WB | R       | R       | R       | R  | R  | R  | R       | Y  | R  | R  | R  | Y  | R  | R  | R                     | Y                     | R                     | R       | R | G | △ |                                   |  |  |  |  |
| CERMAK ROAD<br>END MAST ARM AND FAR LEFT SIGNALS                                  | WB | R       | R       | R       | R  | R  | R  | R<br>←Y | Y  | R  | R  | R  | Y  | R  | R  | R                     | Y                     | R                     | R       | R | G | △ |                                   |  |  |  |  |
| PEDESTRIAN SIGNALS CROSSING CERMAK ROAD<br>ON EAST SIDE OF IL 50 (CICERO AVE.)    |    | H       | H       | H       | FH | H  | FH | H       | H  | H  | H  | H  | H  | H  | H  | H                     | H                     | H                     | H       | H | H | △ |                                   |  |  |  |  |
| PEDESTRIAN SIGNALS CROSSING CERMAK ROAD<br>ON WEST SIDE OF IL 50 (CICERO AVE.)    |    | H       | FH      | H       | H  | H  | FH | H       | H  | H  | H  | H  | H  | H  | H  | H                     | H                     | H                     | H       | H | H | △ |                                   |  |  |  |  |
| PEDESTRIAN SIGNALS CROSSING IL 50 (CICERO<br>AVE.) ON NORTH SIDE OF CERMAK ROAD   |    | H       | H       | H       | H  | H  | H  | H       | FH | H  | H  | H  | FH | H  | H  | H                     | H                     | H                     | H       | H | H | △ |                                   |  |  |  |  |
| PEDESTRIAN SIGNALS CROSSING IL 50 (CICERO<br>AVE.) ON SOUTH SIDE OF CERMAK ROAD   |    | H       | H       | H       | H  | H  | H  | H       | H  | H  | FH | H  | FH | H  | H  | H                     | H                     | H                     | H       | H | H | △ |                                   |  |  |  |  |
|                                                                                   |    HOLD                              |  |  |  |  |

△ RAILROAD PREEMPTION SEQUENCE SHALL PROVIDE THE PROPER CLEARANCE  
INTERVAL TO RESUME THE NORMAL SEQUENCE OF OPERATIONS OR PROPER  
CLEARANCE INTERVAL TO DISPLAY AN EMERGENCY VEHICLE INTERVAL  
(IF APPLICABLE) AFTER RAILROAD PREEMPTION INTERVAL 5 IS TERMINATED.



AMES Engineering, Inc.  
CONSULTING ENGINEERS  
6330 Belmont Road, Suite 4B  
Downers Grove, IL 60516

|            |              |
|------------|--------------|
| USER NAME  | = msomer     |
| PLOT SCALE | = \$SCALE\$  |
| PLOT DATE  | = 03/19/2025 |

|          |   |            |
|----------|---|------------|
| DESIGNED | - | TM         |
| DRAWN    | - | TM, SR     |
| CHECKED  | - | JAR        |
| DATE     | - | 05/23/2024 |

|         |   |
|---------|---|
| REVISED | - |
| REVISED | - |
| REVISED | - |
| REVISED | - |

STATE OF ILLINOIS  
DEPARTMENT OF TRANSPORTATION

SCHEDULE OF QUANTITIES  
CERMAK RD AND IL RTE 50 (CICERO AVE)

|            |                     |              |
|------------|---------------------|--------------|
| SCALE: NTS | SHEET 1 OF 1 SHEETS | STA. TO STA. |
|------------|---------------------|--------------|

|                           |                       |             |                 |              |
|---------------------------|-----------------------|-------------|-----------------|--------------|
| F.A.U<br>RTE.             | SECTION               | COUNTY      | TOTAL<br>SHEETS | SHEET<br>NO. |
| 1453                      | 2020-266-SUR, SW & TS | COOK/DUPAGE | 492             | 310          |
| CONTRACT NO. 62N39        |                       |             |                 |              |
| ILLINOIS FED. AID PROJECT |                       |             |                 |              |

SCHEDULE OF QUANTITIES

| ITEM DESCRIPTION                                                             | UNITS | TOTAL QTY. |
|------------------------------------------------------------------------------|-------|------------|
| UNDERGROUND CONDUIT, GALVANIZED STEEL, 2" DIA.                               | FOOT  | 43         |
| MAINTENANCE OF EXISTING TRAFFIC SIGNAL INSTALLATION                          | EACH  | 1          |
| ELECTRIC CABLE IN CONDUIT, SIGNAL NO. 14 2C                                  | FOOT  | 564        |
| ELECTRIC CABLE IN CONDUIT, SIGNAL NO. 14 5C                                  | FOOT  | 589        |
| ELECTRIC CABLE IN CONDUIT, LEAD-IN, NO. 14 1 PAIR                            | FOOT  | 1103       |
| ELECTRIC CABLE IN CONDUIT, SERVICE, NO. 6 2C                                 | FOOT  | 40         |
| ELECTRIC CABLE IN CONDUIT, EQUIPMENT GROUNDING CONDUCTOR, NO. 6 1C           | FOOT  | 465        |
| CONCRETE OUNDATION, TYPE A                                                   | FOOT  | 4          |
| DRILL EXISTING HANDHOLE                                                      | EACH  | 5          |
| SIGNAL HEAD, LED, 1-FACE, 3-SECTION, MAST ARM MOUNTED                        | EACH  | 2          |
| SIGNAL HEAD, LED, 1-FACE, 3-SECTION, BRACKET MOUNTED                         | EACH  | 3          |
| SIGNAL HEAD, LED, 1-FACE, 5-SECTION, BRACKET MOUNTED                         | EACH  | 1          |
| SIGNAL HEAD, LED, 1-FACE, 5-SECTION, MAST ARM MOUNTED                        | EACH  | 1          |
| PEDESTRIAN SIGNAL HEAD, L.E.D., 1-FACE, BRACKET MOUNTED WITH COUNTDOWN TIMER | EACH  | 8          |
| TRAFFIC SIGNAL BACKPLATE, LOUVERED, FORMED PLASTIC                           | EACH  | 3          |
| INDUCTIVE LOOP DETECTOR                                                      | EACH  | 4          |
| REMOVE EXISTING TRAFFIC SIGNAL EQUIPMENT                                     | EACH  | 1          |
| OUTDOOR RATED NETWORK CABLE                                                  | FOOT  | 79         |
| SERVICE INSTALLATION, GROUND MOUNTED, METERED                                | EACH  | 1          |
| REMOTE CONTROLLED VIDEO SYSTEM                                               | EACH  | 1          |
| PEDESTRIAN SIGNAL POST, 5 FT.                                                | EACH  | 3          |
| LAYER III (NETWORK) SWITCH                                                   | EACH  | 1          |
| FULL-ACTUATED CONTROLLER IN EXISTING CABINET                                 | EACH  | 1          |
| REMOVE AND REPLACE BATTERIES FOR UNINTERRUPTABLE POWER SUPPLY, EXTENDED      | EACH  | 1          |
| ACCESSIBLE PEDESTRIAN SIGNALS                                                | EACH  | 8          |
| CONCRETE FOUNDATION, TYPE A, 12-INCH DIAMETER                                | FOOT  | 12         |
| LED SIGNAL FACE, LENS COVER                                                  | EACH  | 24         |
| CAMERA MOUNTING ASSEMBLY                                                     | EACH  | 1          |
| CENTRACS LICENSE EXPANSION                                                   | EACH  | 1          |
| FIBER OPTIC INTERCONNECT CENTER, 48 PORT                                     | EACH  | 1          |
| LED SIGNAL MODULE REPLACEMENT                                                | EACH  | 17         |





|                        |                         |           |
|------------------------|-------------------------|-----------|
| USER NAME = msomer     | DESIGNED - JMS, MA      | REVISED - |
|                        | DRAWN - JMS, MA, MD, SR | REVISED - |
| PLOT SCALE = \$SCALE\$ | CHECKED - JMA, AS       | REVISED - |
| PLOT DATE = 03/19/2025 | DATE - 11/08/2024       | REVISED - |


**STATE OF ILLINOIS  
DEPARTMENT OF TRANSPORTATION**


**INTERCONNECT PLAN  
CERMAK ROAD**

SCALE: NTS SHEET 1 OF 1 SHEETS STA. TO STA.

**FOR INFORMATION ONLY**

| F.A. RTE.                 | SECTION               | COUNTY       | TOTAL SHEETS | SHEET NO. |
|---------------------------|-----------------------|--------------|--------------|-----------|
| 771                       | 2020-266-SUR, SW & TS | COOK, DUPAGE | 482          | 311       |
| CONTRACT NO. 62N39        |                       |              |              |           |
| ILLINOIS FED. AID PROJECT |                       |              |              |           |

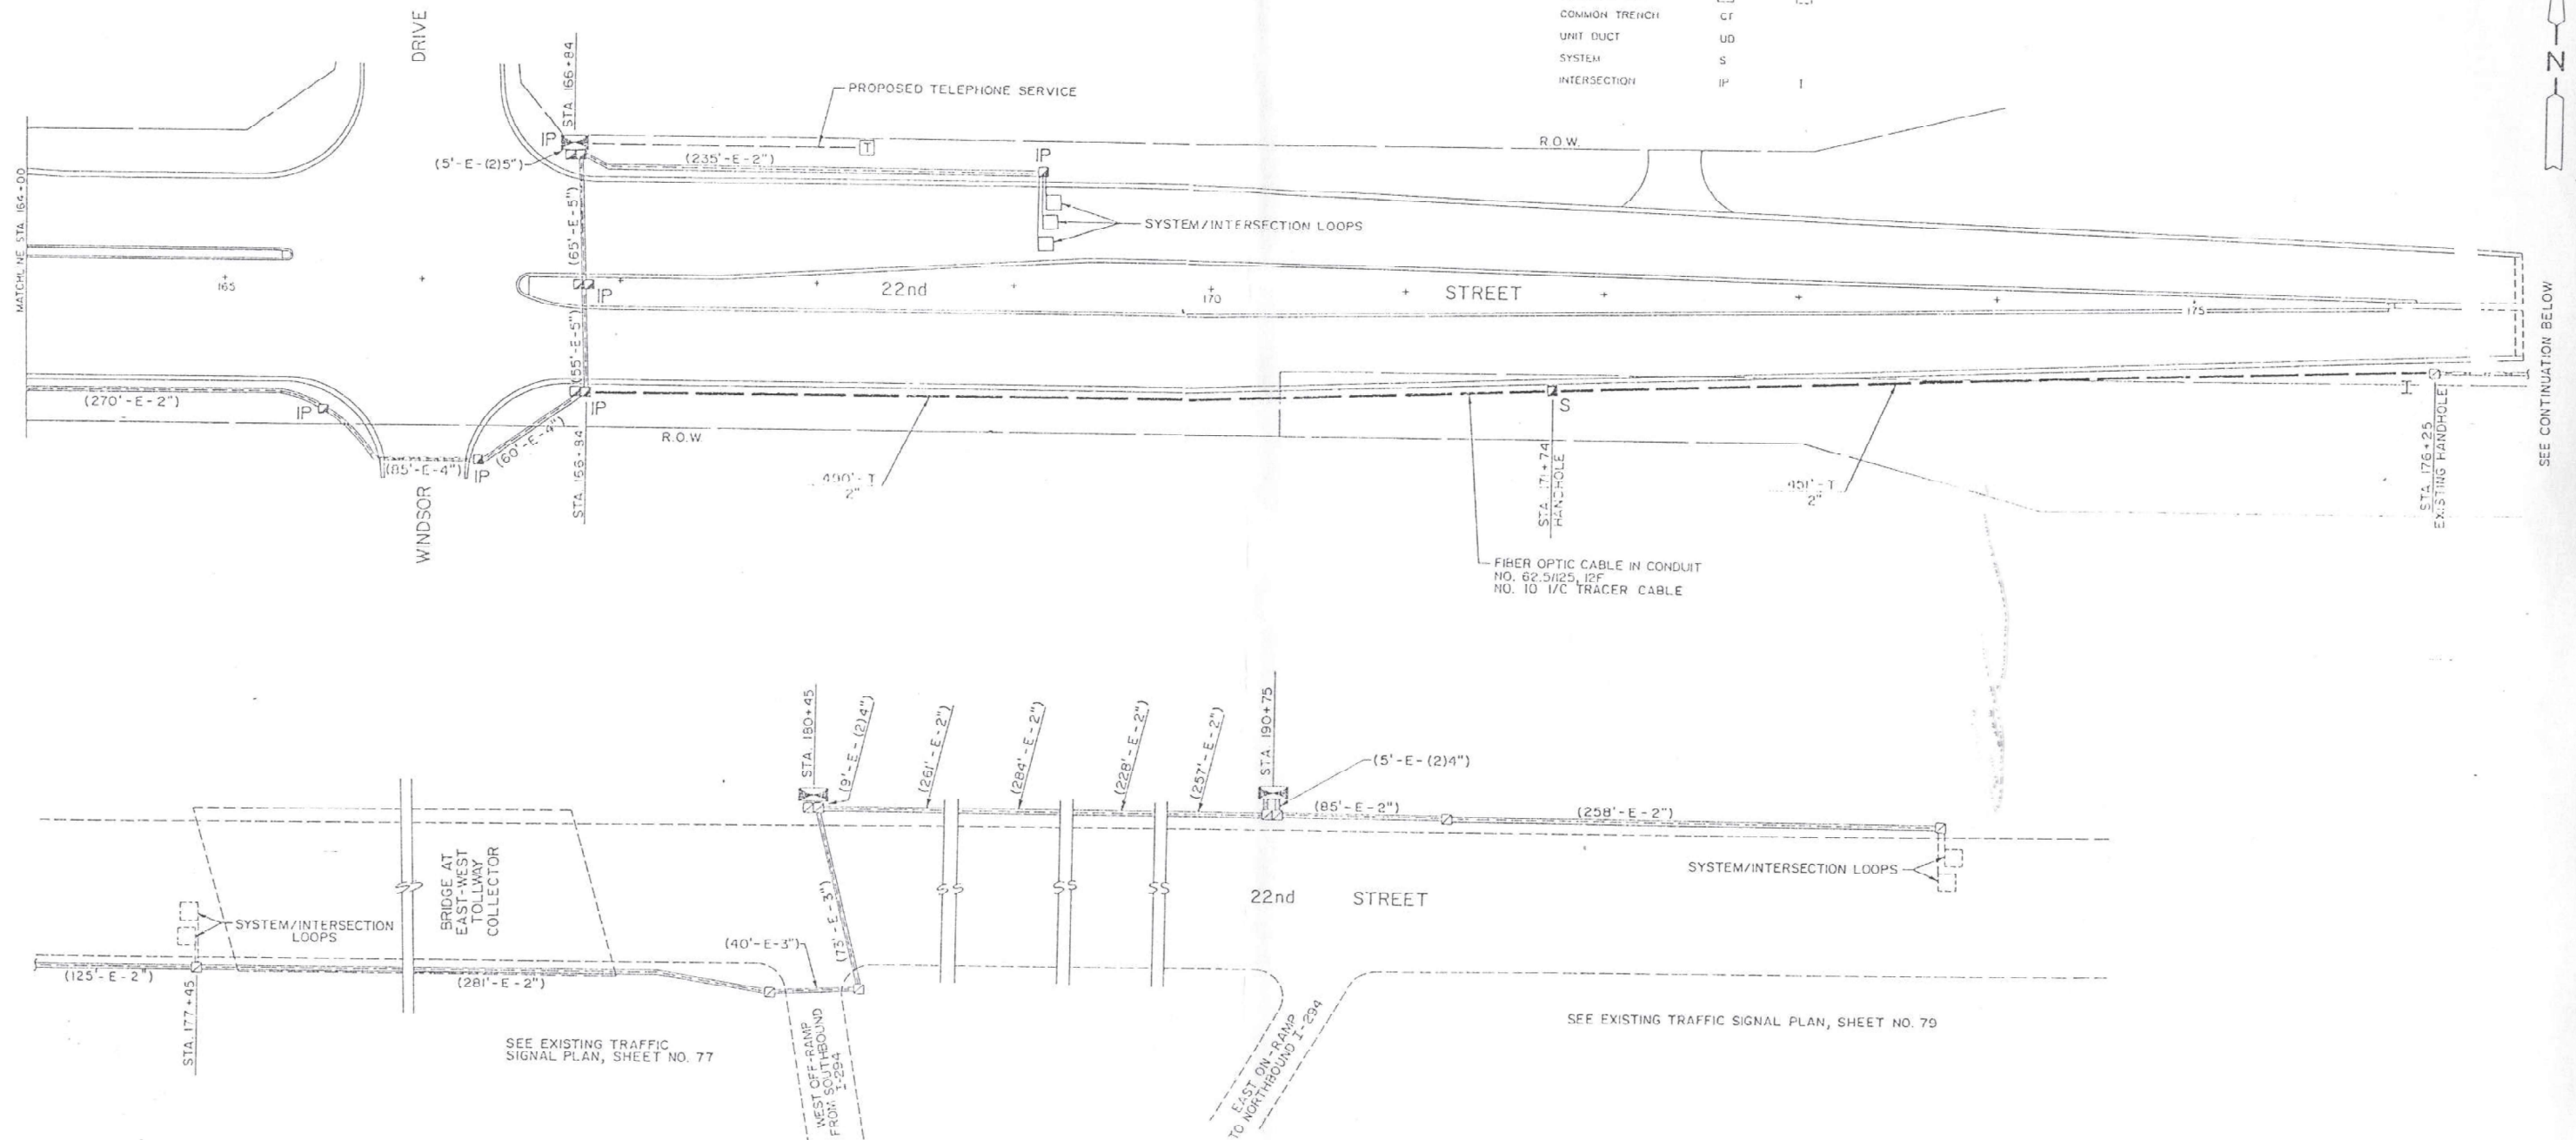

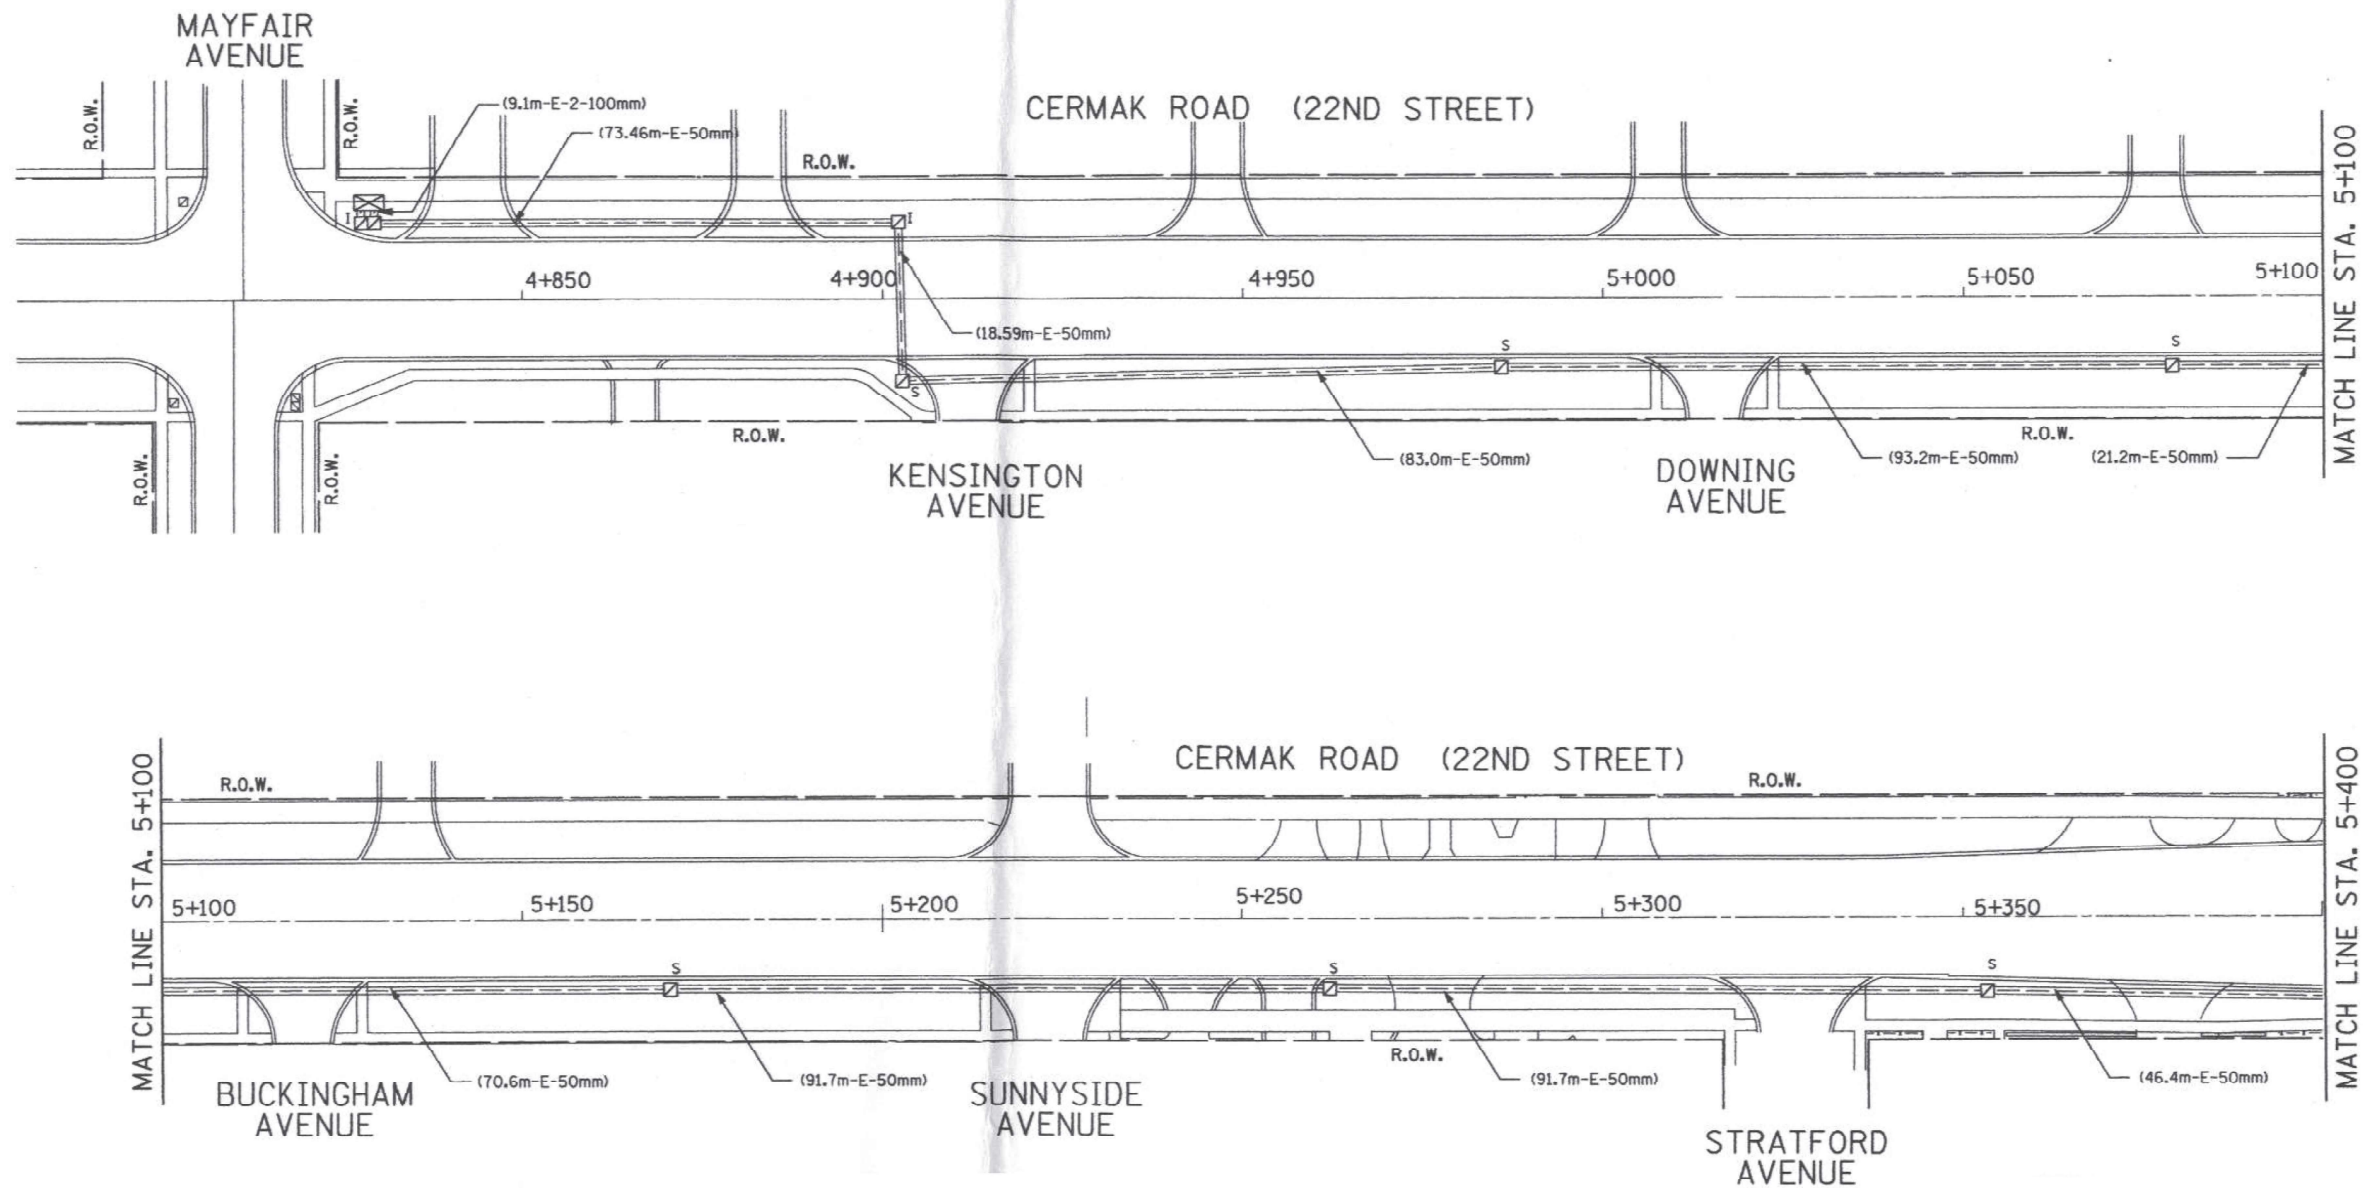

INTERCONNECT PLAN LEGEND

|                                              | PROPOSED | EXISTING |
|----------------------------------------------|----------|----------|
| CONTROLLER                                   |          |          |
| HANDHOLE                                     |          |          |
| HEAVY DUTY HANDHOLE                          |          |          |
| DOUBLE HANDHOLE                              |          |          |
| GALVANIZED STEEL CONDUIT IN TRENCH OR PUSHED |          |          |
| DETECTOR LOOP                                |          |          |
| COMMON TRENCH                                |          |          |
| UNIT DUCT                                    |          |          |
| SYSTEM                                       |          |          |
| INTERSECTION                                 |          |          |
| TELEPHONE CONNECTION                         |          |          |
| SERVICE INSTALLATION                         |          |          |

FOR INFORMATION ONLY

TS SHT NO. 163

AMES Engineering, Inc.  
CONSULTING ENGINEERS  
6330 Belmont Road, Suite 4B  
Downers Grove, IL 60516


|            |              |            |                 |           |  |
|------------|--------------|------------|-----------------|-----------|--|
| USER NAME  | = msomer     | DESIGNED - | JMS, MA         | REVISED - |  |
|            |              | DRAWN -    | JMS, MA, MD, SR | REVISED - |  |
| PLOT SCALE | = \$SCALE\$  | CHECKED -  | JMA, AS         | REVISED - |  |
| PLOT DATE  | = 03/19/2025 | DATE       | = 11/08/2024    | REVISED - |  |

STATE OF ILLINOIS  
DEPARTMENT OF TRANSPORTATION

INTERCONNECT PLAN  
CERMAK ROAD

SCALE: NTS SHEET 1 OF 1 SHEETS STA. TO STA.

|                           |                       |              |              |           |
|---------------------------|-----------------------|--------------|--------------|-----------|
| F.A. RTE.                 | SECTION               | COUNTY       | TOTAL SHEETS | SHEET NO. |
| 771                       | 2020-266-SUR, SW & TS | COOK, DUPAGE | 482          | 312       |
| CONTRACT NO. 62N39        |                       |              |              |           |
| ILLINOIS FED. AID PROJECT |                       |              |              |           |

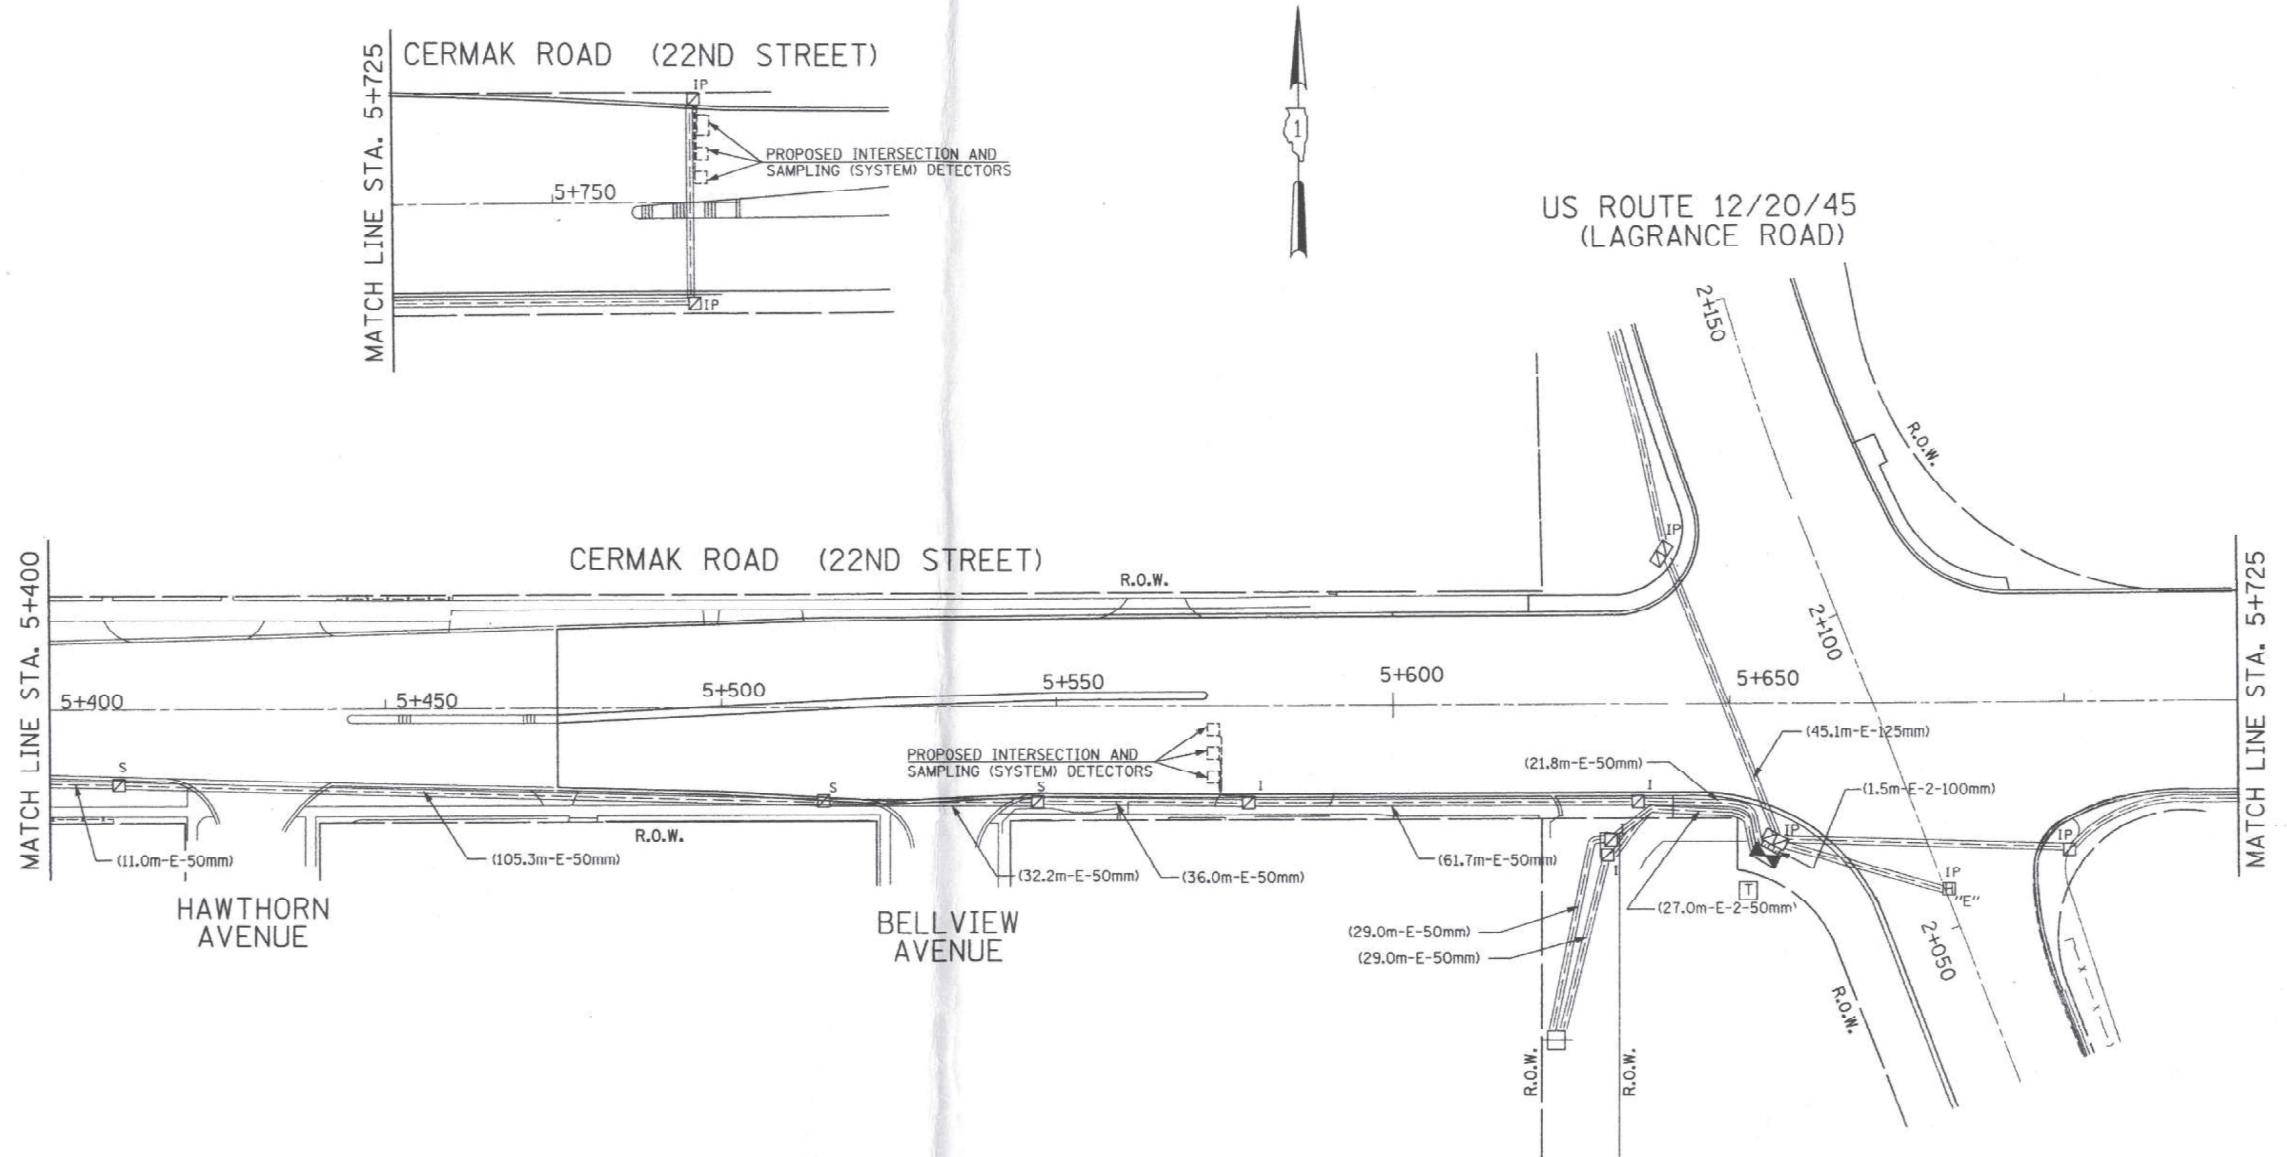

INTERCONNECT PLAN LEGEND

- CONTROLLER  
HANDHOLE  
HEAVY DUTY HANDHOLE  
DOUBLE HANDHOLE  
GALVANIZED STEEL CONDUIT IN TRENCH OR PUSHED  
DETECTOR LOOP  
COMMON TRENCH  
UNIT DUCT  
SYSTEM  
INTERSECTION  
TELEPHONE CONNECTION  
SERVICE INSTALLATION

| PROPOSED | EXISTING |
|----------|----------|
|          |          |
|          |          |
FOR INFORMATION ONLY

TS SHT NO. 164

MODEL NAME: D:\2025\91B-BR\TS164-INTERCONNECT.dgn

AMES Engineering, Inc.  
CONSULTING ENGINEERS  
6330 Belmont Road, Suite 4B  
Downers Grove, IL 60516

|            |                   |          |                   |         |   |
|------------|-------------------|----------|-------------------|---------|---|
| USER NAME  | = msomer          | DESIGNED | - JMB, MA         | REVISED | - |
| DRAWN      | - JMB, MA, MD, SR | DRAWN    | - JMB, MA, MD, SR | REVISED | - |
| PLOT SCALE | = \$SCALE\$       | CHECKED  | - JMB, AS         | REVISED | - |
| PLOT DATE  | = 03/19/2025      | DATE     | - 11/08/2024      | REVISED | - |

STATE OF ILLINOIS  
DEPARTMENT OF TRANSPORTATION

INTERCONNECT PLAN  
CERMAK ROAD

SCALE: NTS SHEET 1 OF 1 SHEETS STA. TO STA.



|           |                       |              |                  |           |
|-----------|-----------------------|--------------|------------------|-----------|
| F.A. RTE. | SECTION               | COUNTY       | TOTAL SHEETS     | SHEET NO. |
| 771       | 2020-266-SUR, SW & TS | COOK, DUPAGE | 482              | 313       |
| ILLINOIS  |                       |              | FED. AID PROJECT |           |

CONTRACT NO. 62N39





| FILE<br>DATE          | SECTION    | COUNTY             | TOTAL<br>SHEETS   | SHEET<br>NO. |
|-----------------------|------------|--------------------|-------------------|--------------|
| 1450                  | 1095-118TG | COOK               | 47                | 42           |
| STA 39+00             |            | TO STA 67+00/31+00 |                   |              |
| FED. ROAD DIST. NO. 7 |            | PLAN/REV.          | FED. AID PROJECT. |              |
| C-91-168-95           |            |                    |                   |              |

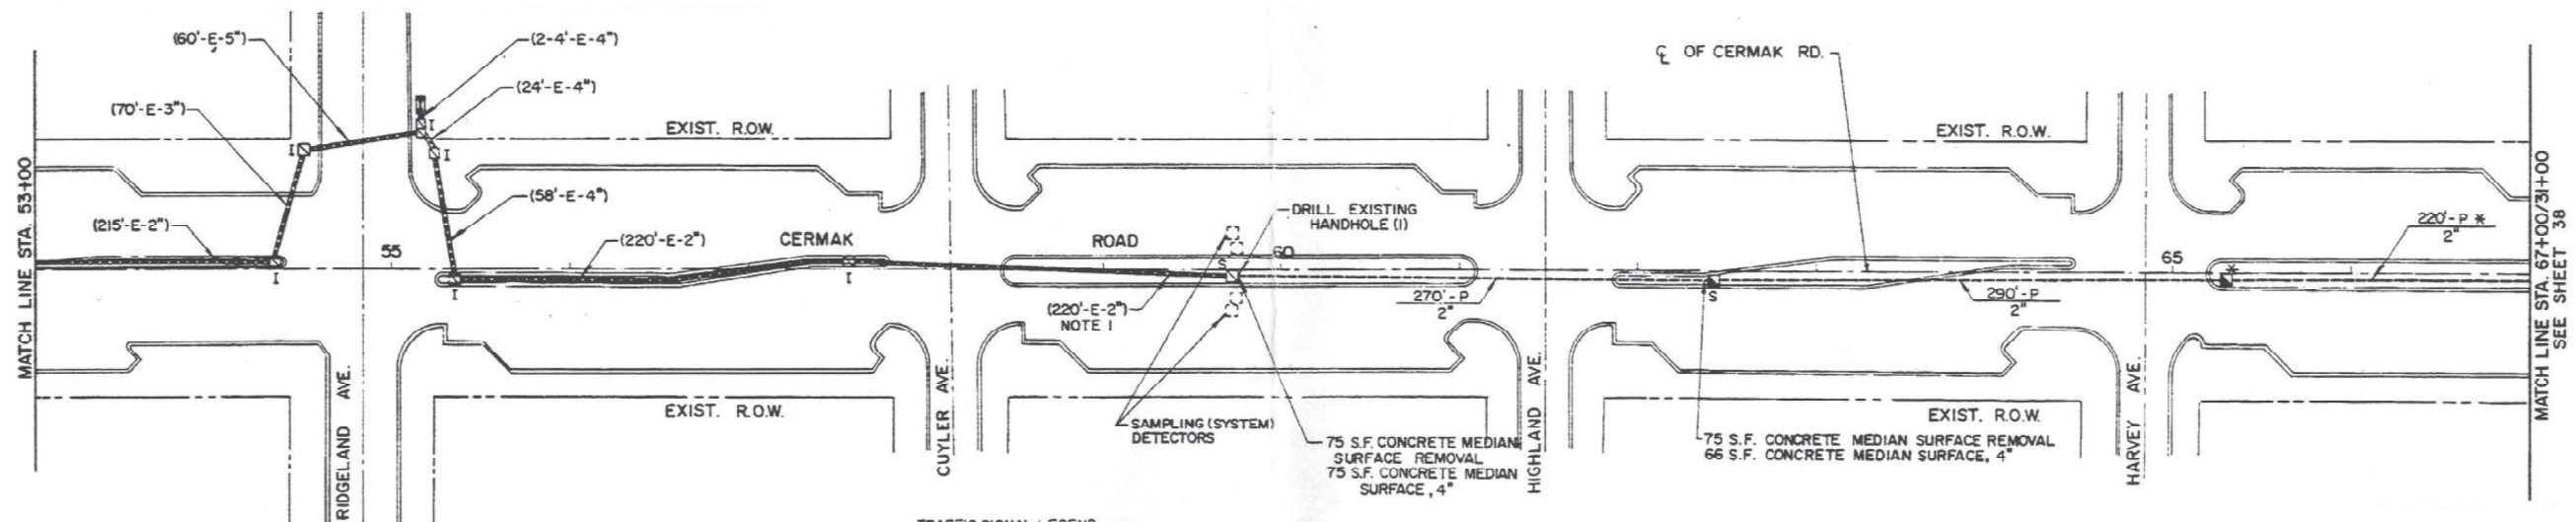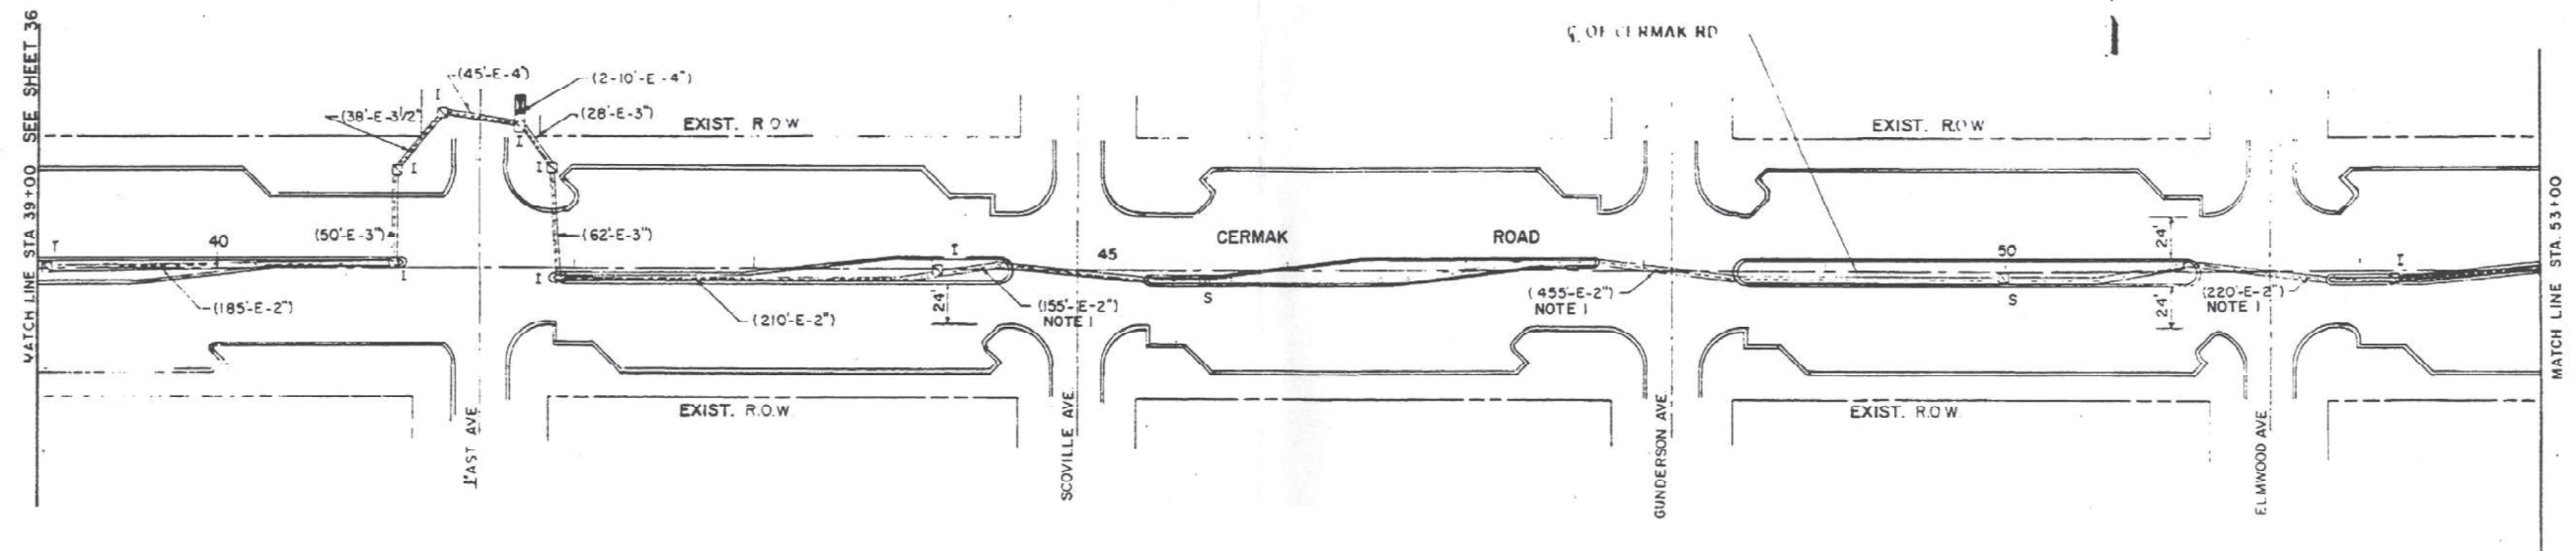

### TRAFFIC SIGNAL LEGEND

CONTROLLER  
SERVICE INSTALLATION  
HANDHOLE  
HEAVY DUTY HANDHOLE  
DOUBLE HANDHOLE  
G.S. CONDUIT IN TRENCH OR PUSHED  
DETECTOR LOOP  
SYSTEM  
INTERSECTION

| PROPOSED | EXISTING |
|----------|----------|
|          |          |
|          |          |
|          |          |
|          |          |
|          |          |
| <hr/>    |          |
|          |          |
| S        | S        |
| I        | I        |

**FOR INFORMATION ONLY**

TS SHT NO. 166

MODEL: \$MODELNAME\$  
FILE NAME: D162N39-sht-TS166-INTERCONNECT.dgn



|                        |                                    |           |
|------------------------|------------------------------------|-----------|
| USER NAME = msomer     | DESIGNED - <del>MB</del> , MA      | REVISED - |
|                        | DRAWN - <del>MS</del> , MA, MD, SR | REVISED - |
| PLOT SCALE = \$SCALE\$ | CHECKED - <del>JRA</del> , AS      | REVISED - |
| PLOT DATE = 03/19/2025 | DATE - 11/08/2024                  | REVISED - |

**STATE OF ILLINOIS  
DEPARTMENT OF TRANSPORTATION**

**INTERCONNECT PLAN  
GERMAK ROAD**

|            |                     |              |
|------------|---------------------|--------------|
| SCALE: NTS | SHEET 1 OF 1 SHEETS | STA. TO STA. |
|------------|---------------------|--------------|

[illegible]






|                        |                                |           |
|------------------------|--------------------------------|-----------|
| USER NAME = msomer     | DESIGNED - <b>MS</b> , MA      | REVISED - |
|                        | DRAWN - <b>MS</b> , MA, MD, SR | REVISED - |
| PLOT SCALE = \$SCALE\$ | CHECKED - <b>JWA</b> , AS      | REVISED - |
| PLOT DATE = 03/19/2025 | DATE - 11/08/2024              | REVISED - |

**STATE OF ILLINOIS  
DEPARTMENT OF TRANSPORTATION**

**INTERCONNECT PLAN  
CERMAK ROAD**

SCALE: NTS SHEET 1 OF 1 SHEETS STA. TO STA.

| F.A. RTE.                 | SECTION               | COUNTY       | TOTAL SHEETS | SHEET NO. |
|---------------------------|-----------------------|--------------|--------------|-----------|
| 771                       | 2020-266-SUR, SW & TS | COOK, DUPAGE | 492          | 316       |
| CONTRACT NO. 62N39        |                       |              |              |           |
| ILLINOIS FED. AID PROJECT |                       |              |              |           |

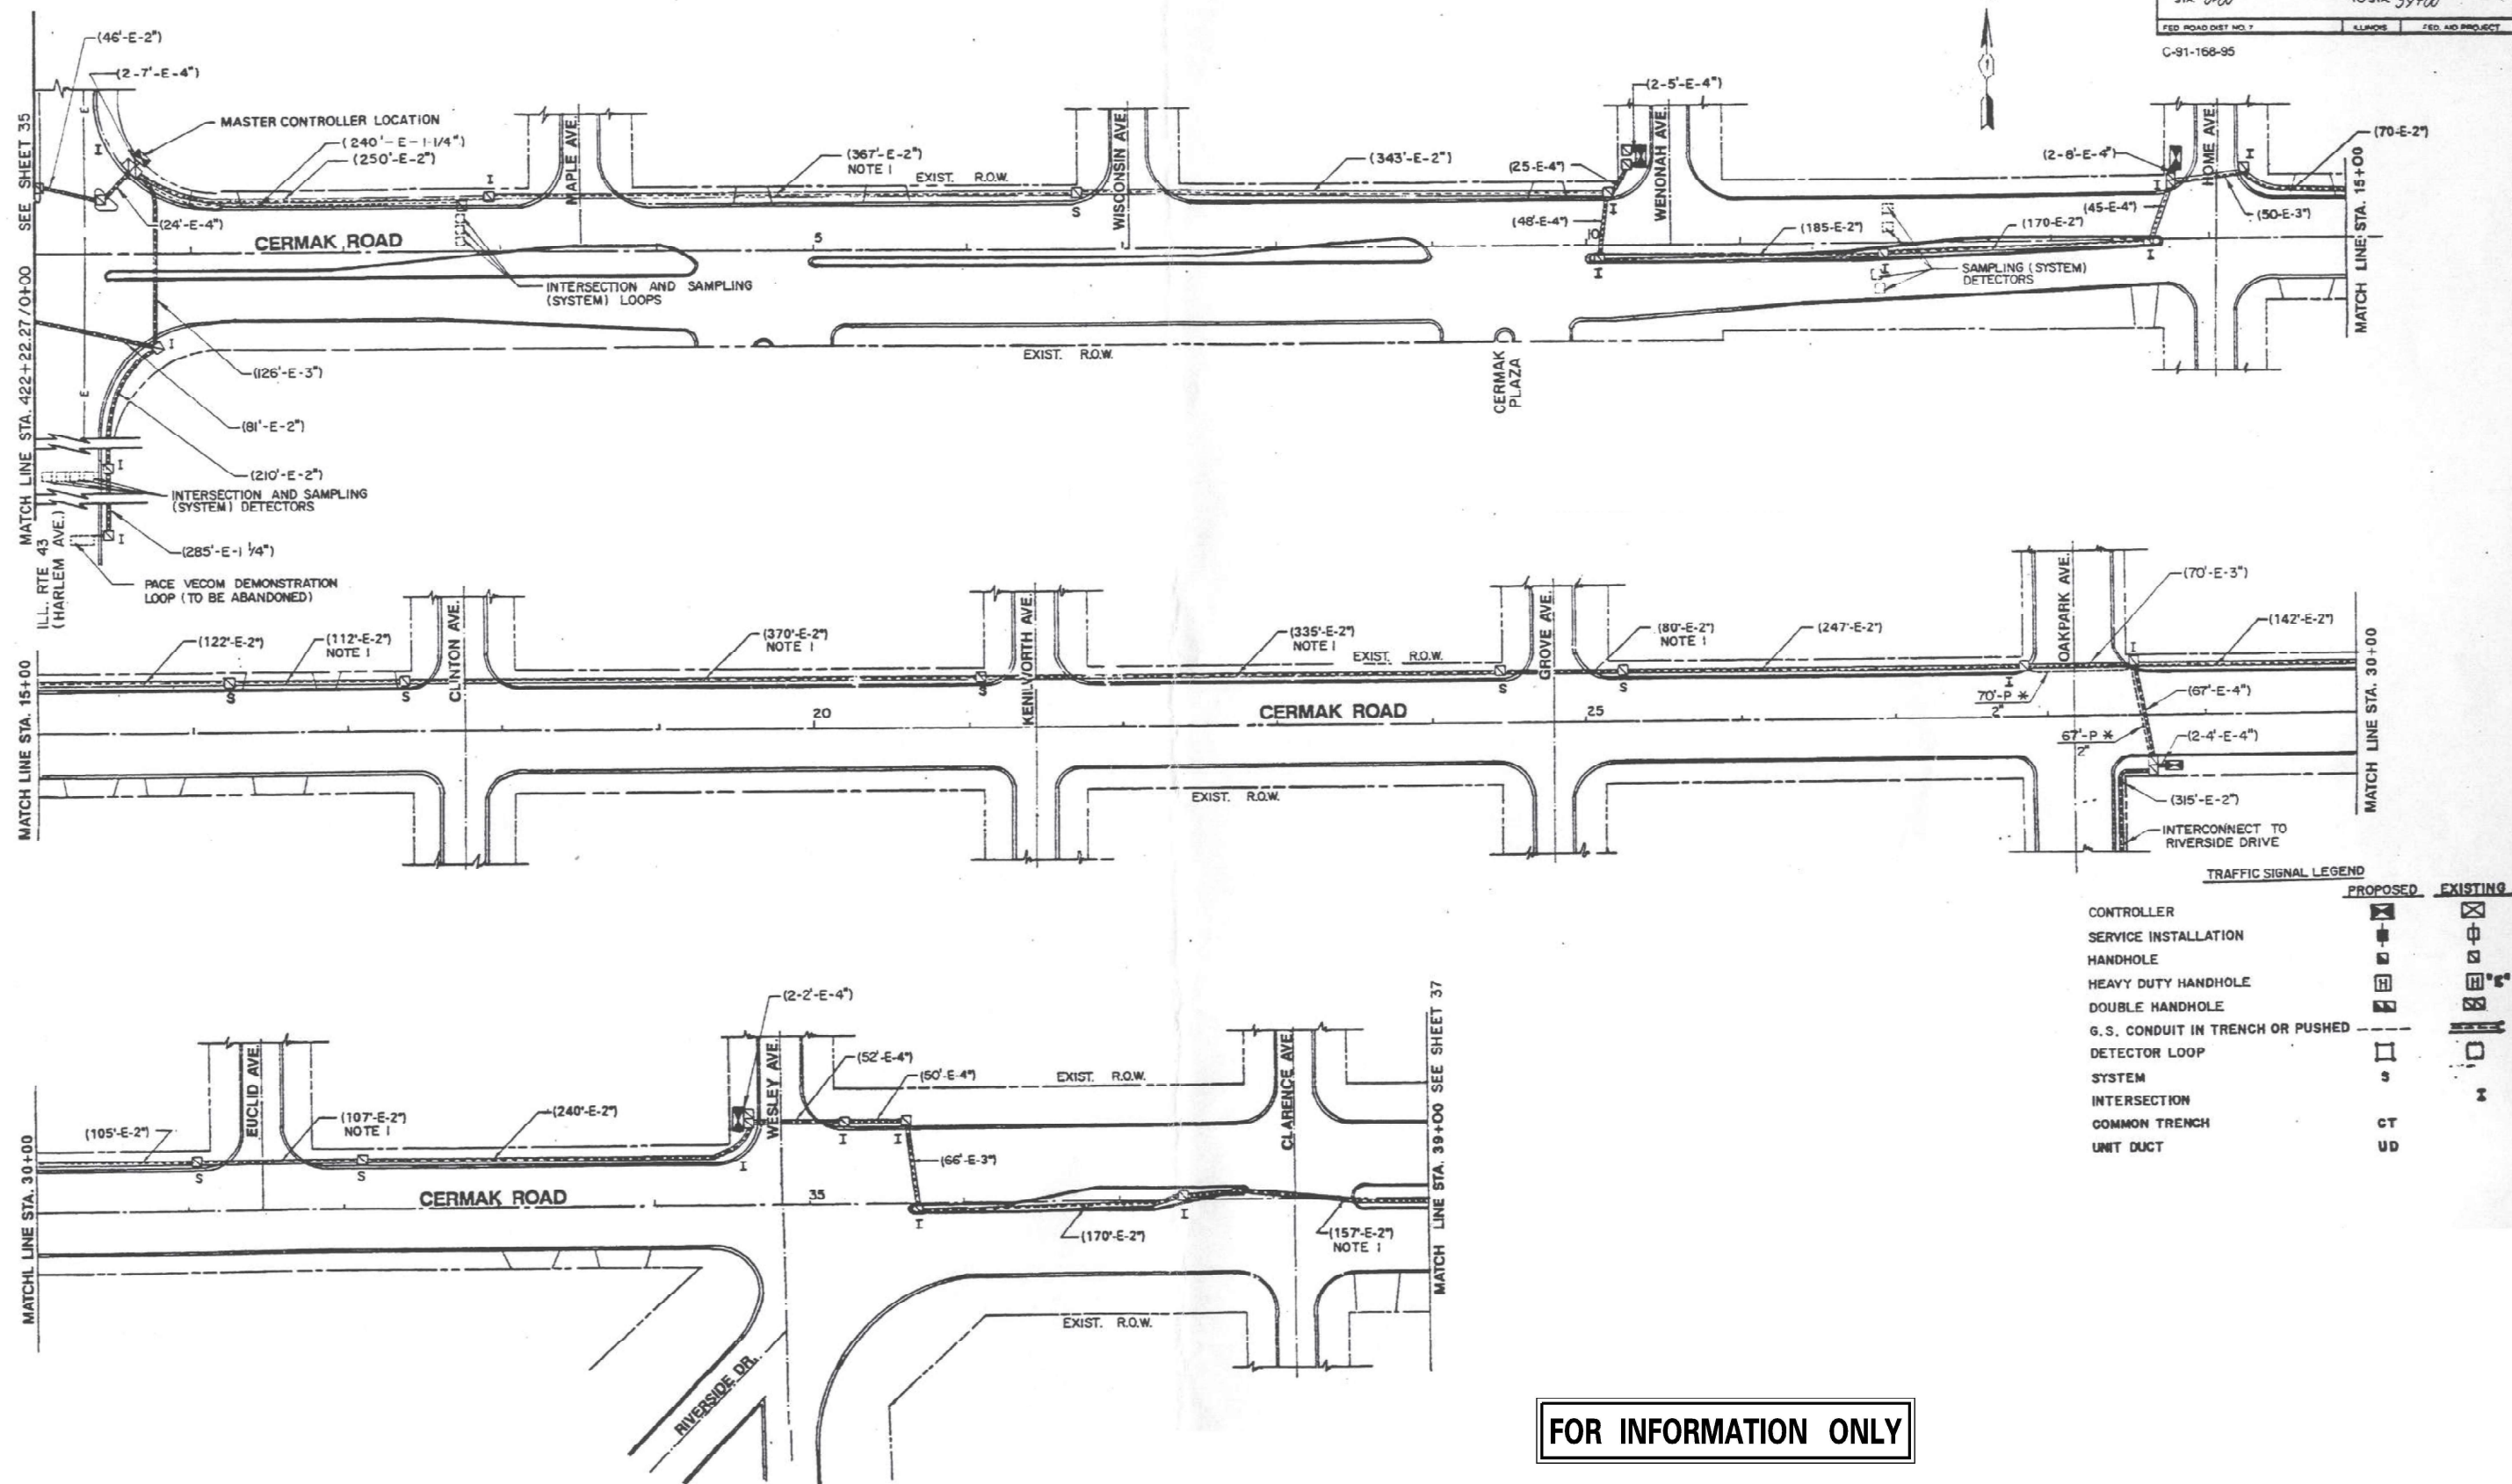

**FOR INFORMATION ONLY**



|           |                  |          |           |         |   |
|-----------|------------------|----------|-----------|---------|---|
| USER NAME | = msomer         | DESIGNED | - JMB, MA | REVISED | - |
| DRAWN     | - MS, MA, MD, SR | REVIS    | -         |         |   |
| CHECKED   | - JMA, AS        | REVIS    | -         |         |   |
| DATE      | - 11/08/2024     | REVIS    | -         |         |   |


STATE OF ILLINOIS  
DEPARTMENT OF TRANSPORTATION

INTERCONNECT PLAN  
CERMAK ROAD

SCALE: NTS SHEET 1 OF 1 SHEETS STA. TO STA.

|                           |                       |              |              |           |
|---------------------------|-----------------------|--------------|--------------|-----------|
| F.A. RTE.                 | SECTION               | COUNTY       | TOTAL SHEETS | SHEET NO. |
| 771                       | 2020-266-SUR, SW & TS | COOK, DUPAGE | 482          | 317       |
| CONTRACT NO. 62N39        |                       |              |              |           |
| ILLINOIS FED. AID PROJECT |                       |              |              |           |

FOR INFORMATION ONLY

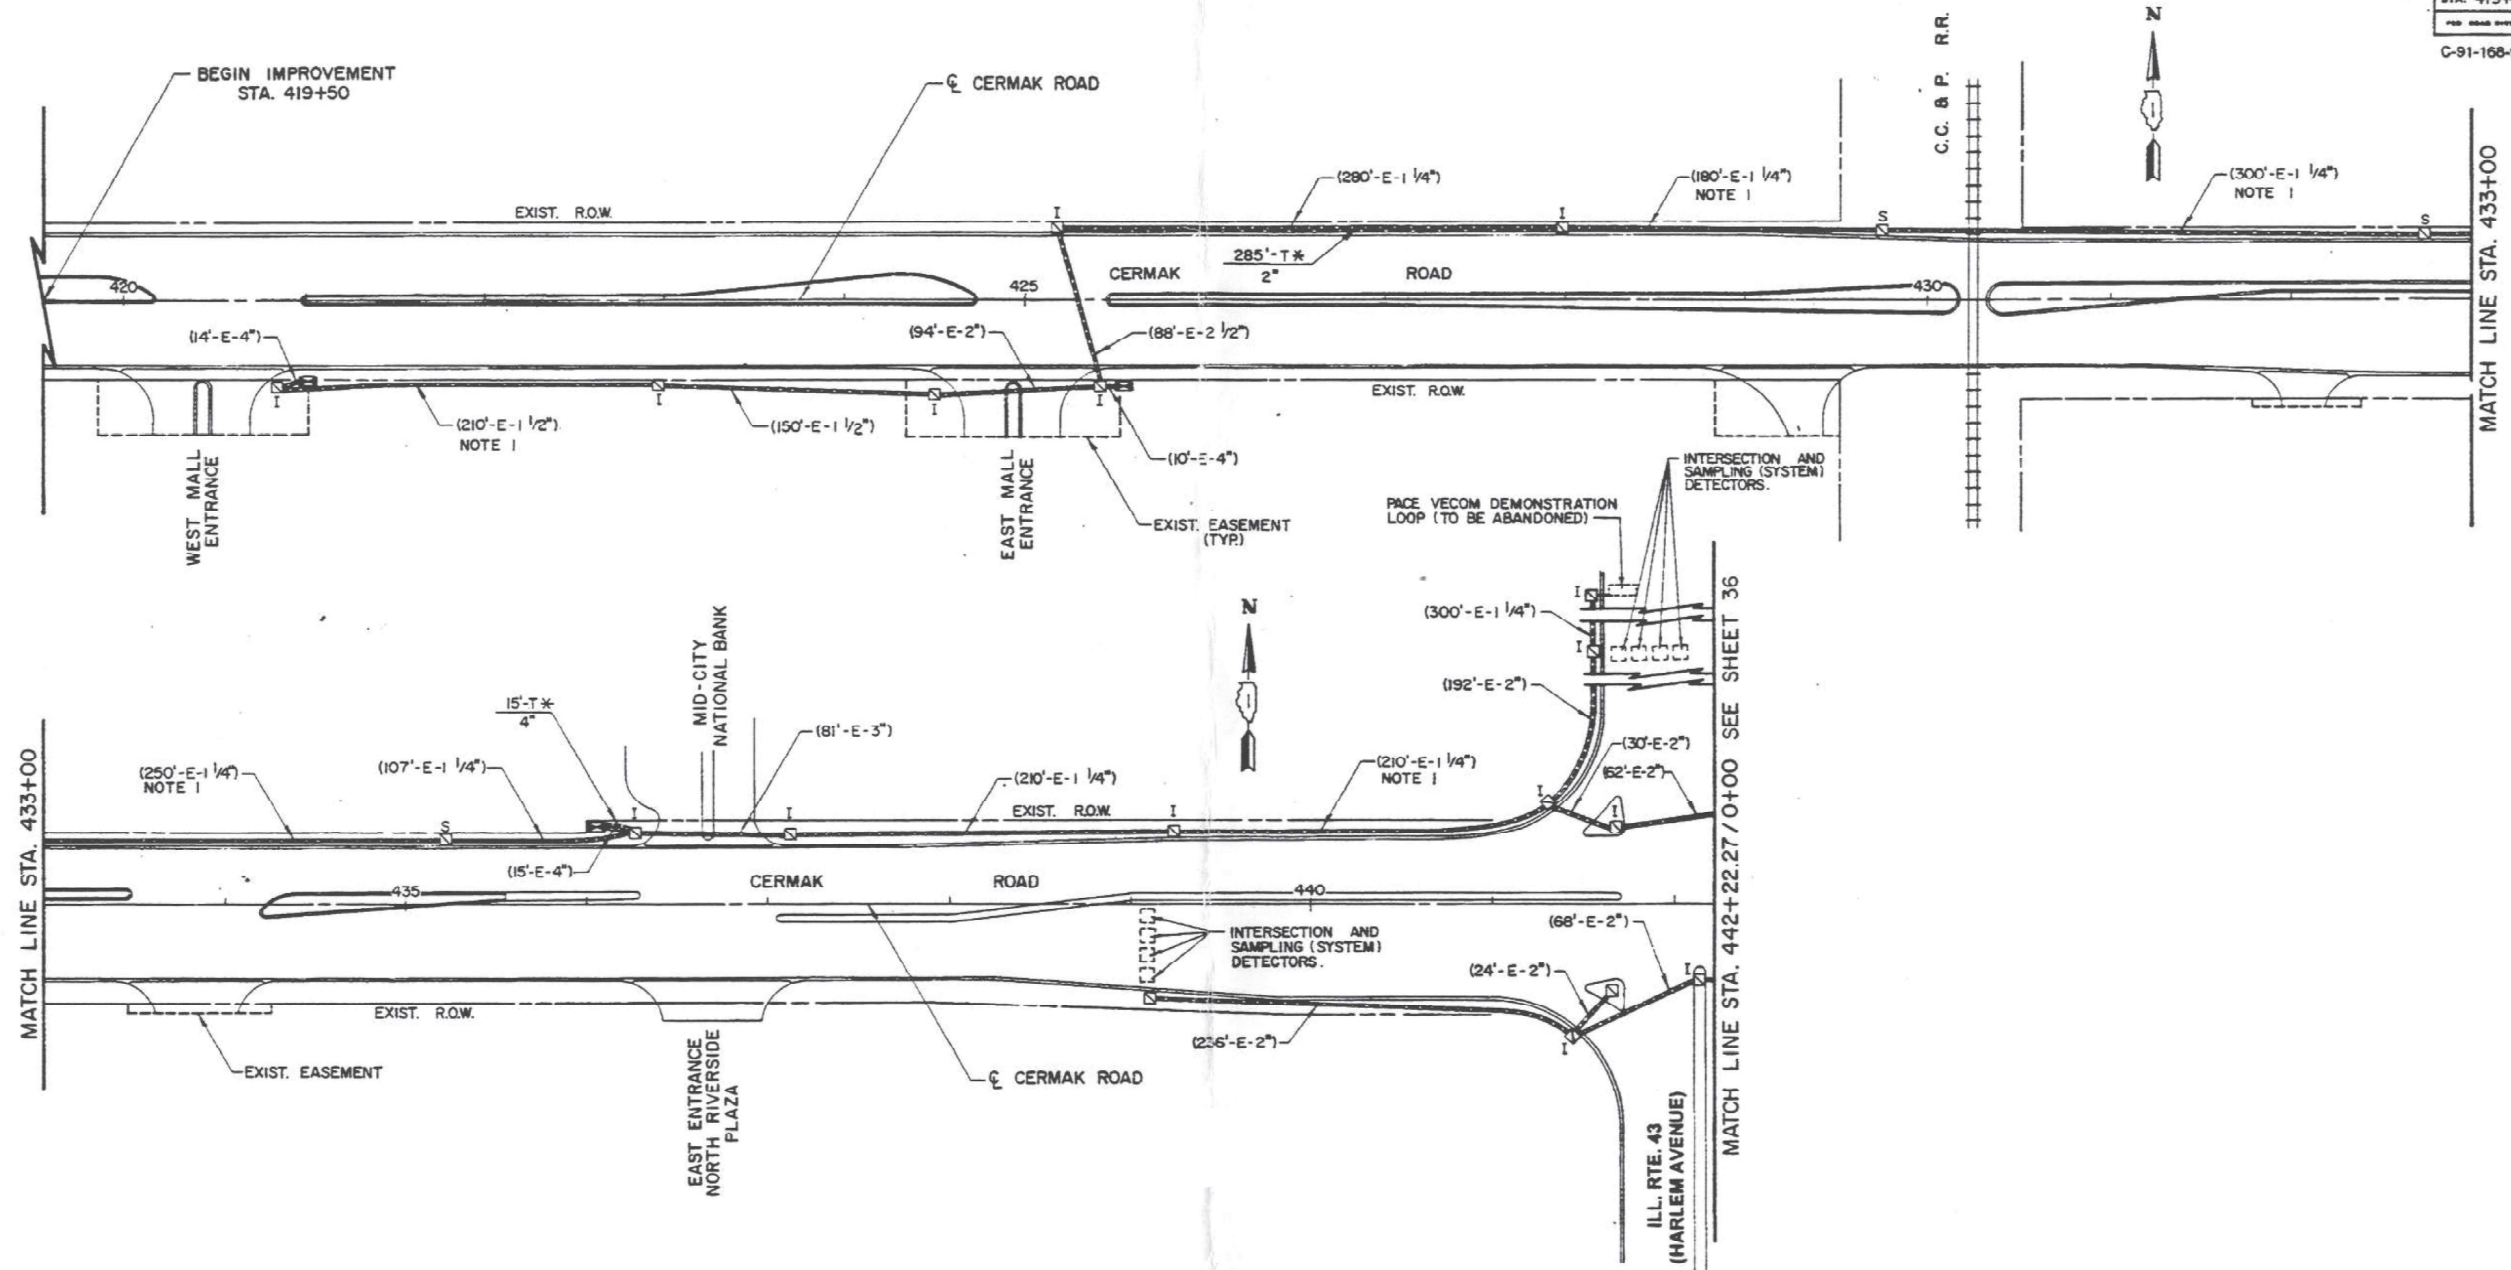

TRAFFIC SIGNAL LEGEND

CONTROLLER  
SERVICE INSTALLATION  
HANDHOLE  
HEAVY DUTY HANDHOLE  
DOUBLE HANDHOLE  
G.S. CONDUIT IN TRENCH OR PUSHED  
DETECTOR LOOP  
SYSTEM  
INTERSECTION

| PROPOSED | EXISTING |
|----------|----------|
|          |          |
|          |          |
| FAU<br>RTE.            | SECTION    | COUNTY                 | TOTAL<br>SHEETS   | SHEET<br>NO. |
|------------------------|------------|------------------------|-------------------|--------------|
| 1453                   | 1995-118TS | COOK                   | 47                | 40           |
| STA. 419+50            |            | TO STA. 442+22.27/0+00 |                   |              |
| FED. ROAD DIST. AND T. |            | PLANNED                | FED. AID PROJECT. |              |
| C-91-168-95            |            |                        |                   |              |






|            |              |            |                |           |  |
|------------|--------------|------------|----------------|-----------|--|
| USER NAME  | = msomer     | DESIGNED - | MS, MA         | REVISED - |  |
|            |              | DRAWN -    | MS, MA, MD, SR | REVISED - |  |
| PLOT SCALE | = \$SCALE\$  | CHECKED -  | JPR, AS        | REVISED - |  |
| PLOT DATE  | = 03/19/2025 | DATE       | = 11/08/2024   | REVISED - |  |

STATE OF ILLINOIS  
DEPARTMENT OF TRANSPORTATION

INTERCONNECT SCHEMATIC (SHEET 1 OF 2)  
CERMAK RD FROM WINDSOR DR TO CICERO AVE

SCALE: NTS SHEET 1 OF 1 SHEETS STA. TO STA.

| F.A. RTE.                 | SECTION               | COUNTY       | TOTAL SHEETS | SHEET NO. |
|---------------------------|-----------------------|--------------|--------------|-----------|
| 771                       | 2020-266-SUR, SW & TS | COOK, DUPAGE | 492          | 318       |
| CONTRACT NO. 62N39        |                       |              |              |           |
| ILLINOIS FED. AID PROJECT |                       |              |              |           |

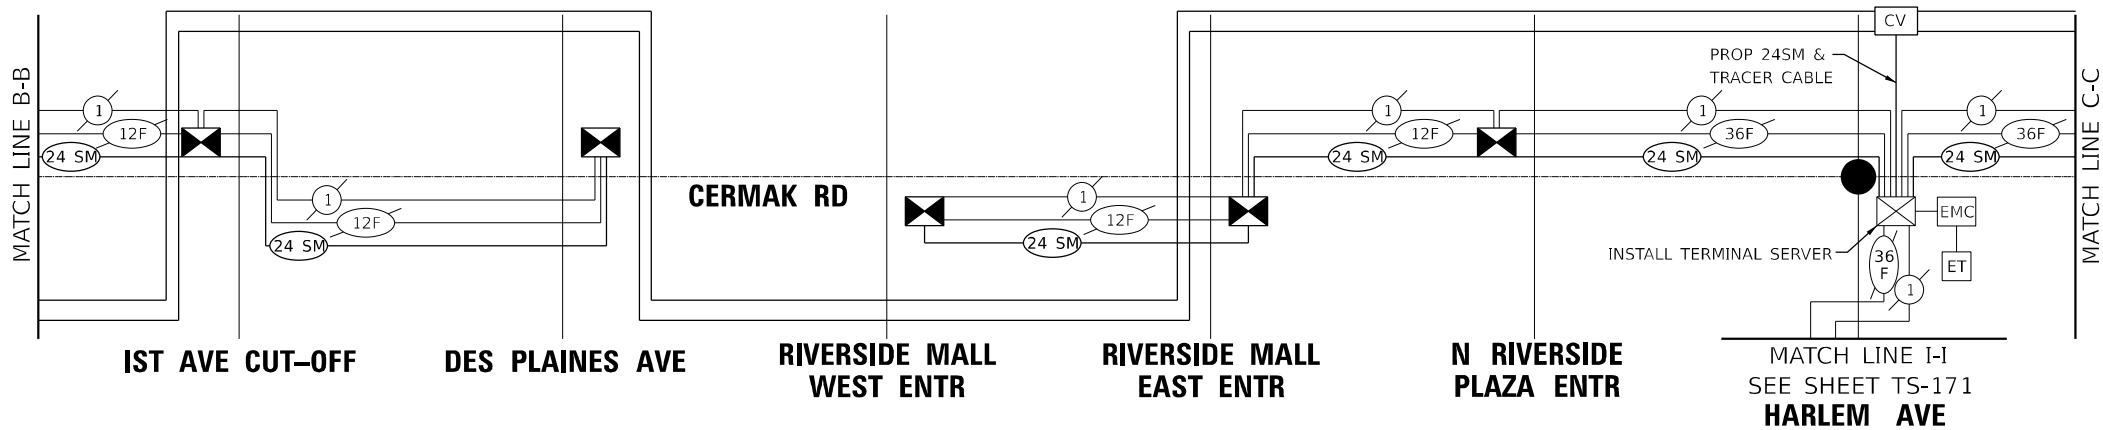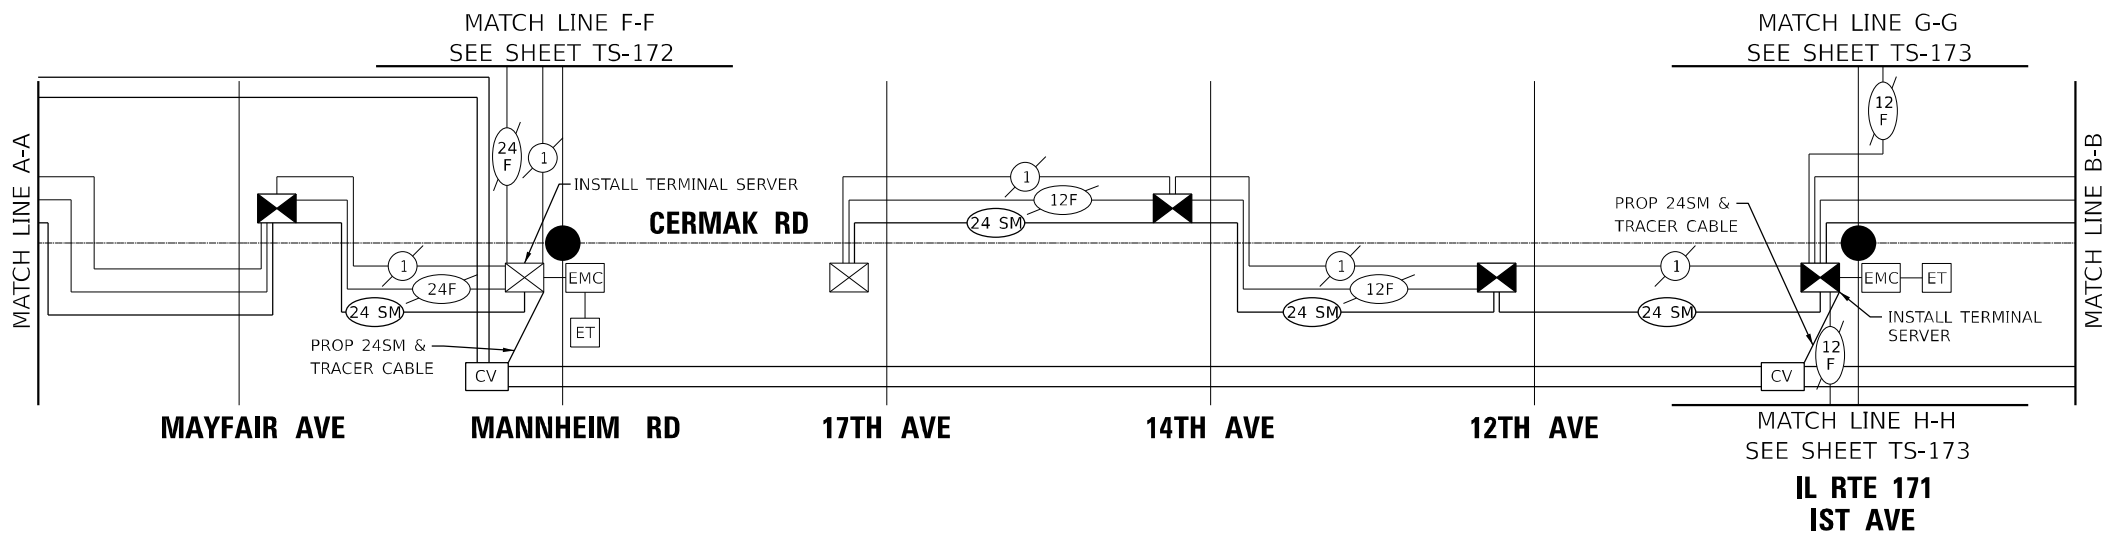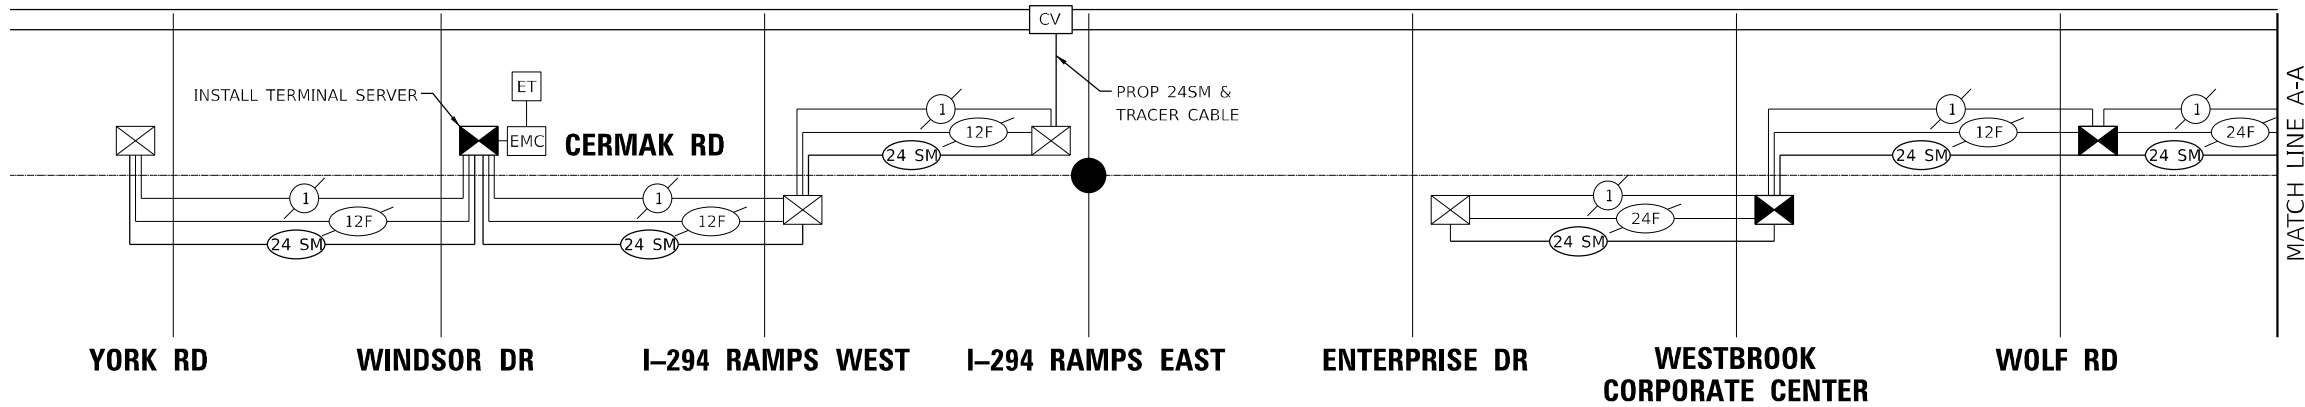

PROPOSED LAYER III NETWORK SWITCH

NOTES:

- COORDINATE IMPROVEMENTS WITH CONTRACT 62N32.
- THE INTERSECTION OF CERMAK ROAD AND MANNHEIM ROAD SHALL REMAIN ON THE IDOT CLOSED SYSTEM ECON 103.
- COORDINATE IMPROVEMENTS WITH CONTRACT 62J47 FOR IMPROVEMENTS FROM N RIVERSIDE PLAZA ENTR TO WENONAH AVE.
- THE INTERSECTION OF CERMAK ROAD AND IL 50 (CICERO AVE) SHALL REMAIN ON THE IDOT CLOSED LOOP SYSTEM ECON 108.

IDOT CENTRACS





|                        |                                |           |
|------------------------|--------------------------------|-----------|
| USER NAME = msomer     | DESIGNED - <b>MS</b> , MA      | REVISED - |
|                        | DRAWN - <b>MS</b> , MA, MD, SR | REVISED - |
| PLOT SCALE = \$SCALE\$ | CHECKED - <b>JWA</b> , AS      | REVISED - |
| PLOT DATE = 03/19/2025 | DATE - 11/08/2024              | REVISED - |


STATE OF ILLINOIS  
DEPARTMENT OF TRANSPORTATION

INTERCONNECT SCHEMATIC (SHEET 2 OF 2)  
CERMAK RD FROM WINDSOR DR TO CICERO AVE

SCALE: NTS      SHEET 1 OF 1 SHEETS      STA.      TO STA.


| F.A. RTE.                 | SECTION               | COUNTY       | TOTAL SHEETS | SHEET NO. |
|---------------------------|-----------------------|--------------|--------------|-----------|
| 771                       | 2020-266-SUR, SW & TS | COOK, DUPAGE | 4192         | 319       |
| CONTRACT NO. 62N39        |                       |              |              |           |
| ILLINOIS FED. AID PROJECT |                       |              |              |           |

IDOT CENTRACS

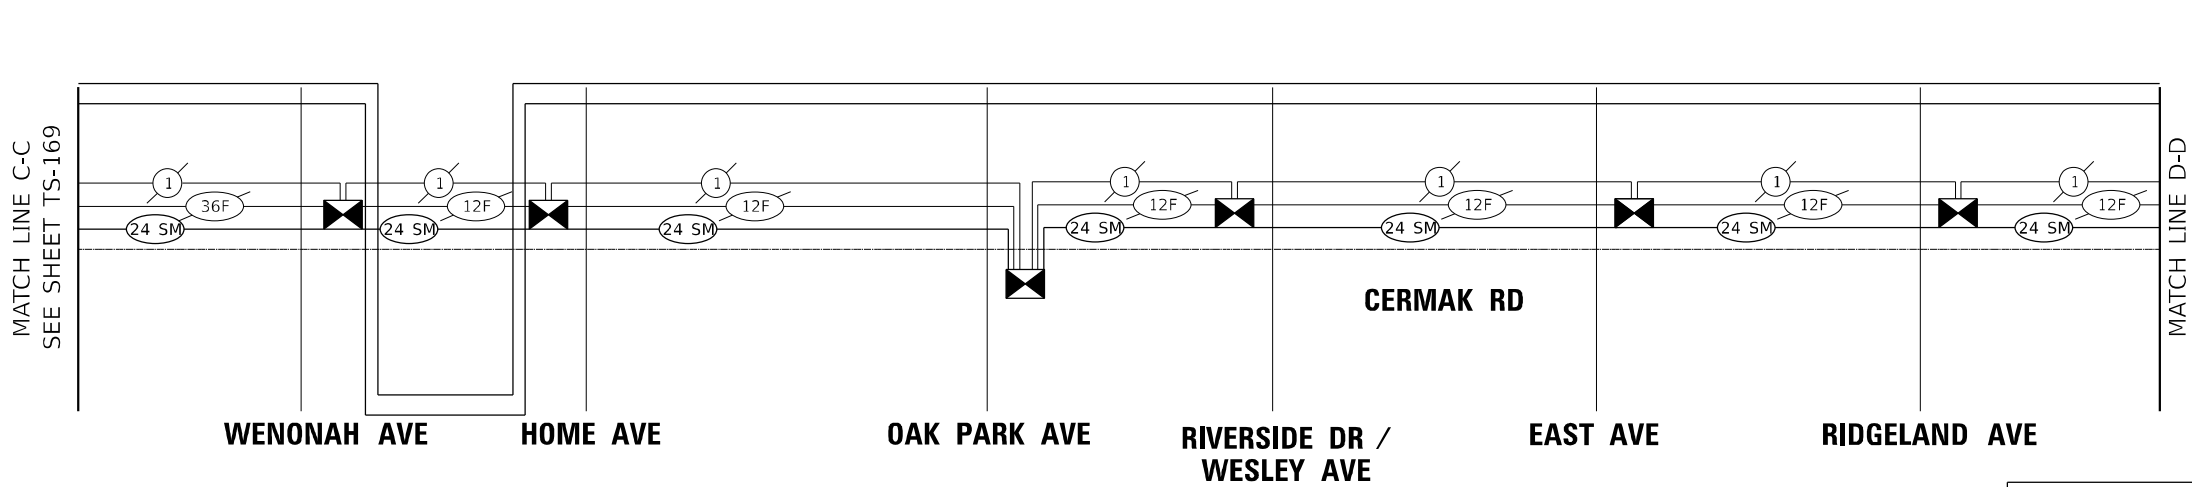


SCHEDULE OF QUANTITIES

| ITEM DESCRIPTION                                  | UNITS | TOTAL QTY |
|---------------------------------------------------|-------|-----------|
| REMOVE ELECTRIC CABLE FROM CONDUIT                | FOOT  | 88588     |
| TERMINAL SERVER                                   | EACH  | 4         |
| FIBER OPTIC CABLE IN CONDUIT, NO. 62.5/125, 12F   | FOOT  | 1121      |
| FIBER OPTIC CABLE IN CONDUIT, NO. 62.5/125, SM24F | FOOT  | 44294     |
| TERMINATE FIBER IN CABINET                        | EACH  | 444       |
| SPLICE FIBER IN CABINET                           | EACH  | 198       |

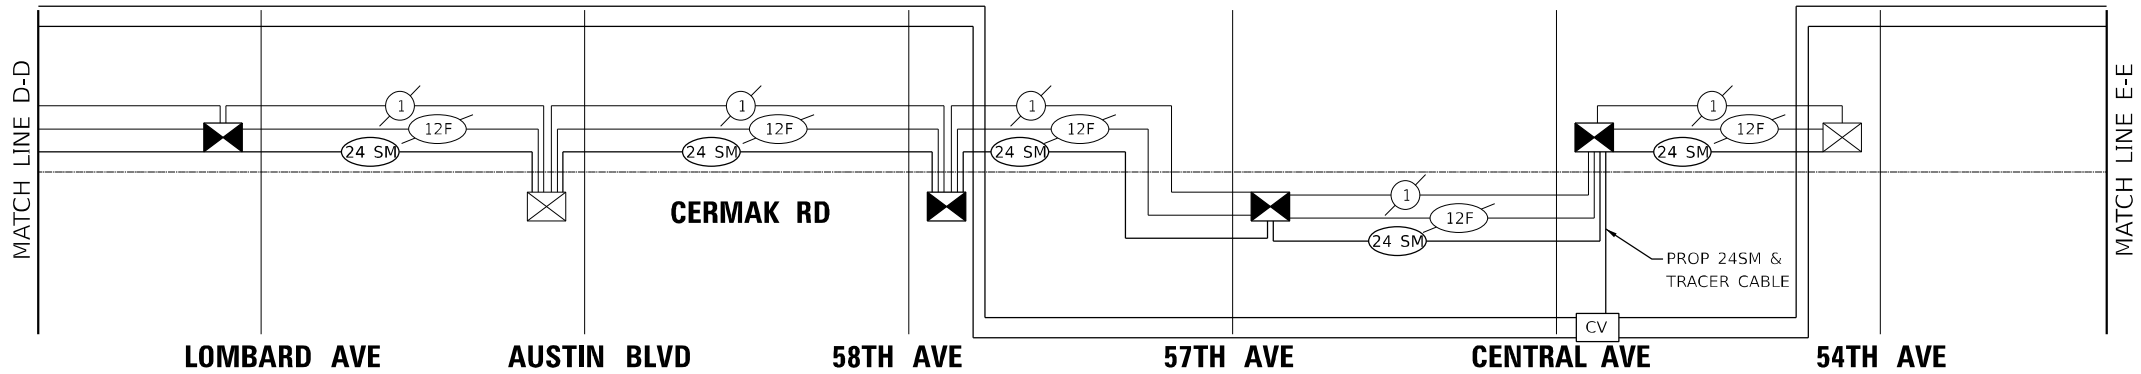

NOTES:

- COORDINATE IMPROVEMENTS WITH CONTRACT 62N32.
- THE INTERSECTION OF CERMAK ROAD AND MANNHEIM ROAD SHALL REMAIN ON THE IDOT CLOSED SYSTEM ECON 103.
- COORDINATE IMPROVEMENTS WITH CONTRACT 62J47 FOR IMPROVEMENTS FROM N RIVERSIDE PLAZA ENTR TO WENONAH AVE.
- THE INTERSECTION OF CERMAK ROAD AND IL 50 (CICERO AVE) SHALL REMAIN ON THE IDOT CLOSED LOOP SYSTEM ECON 108.

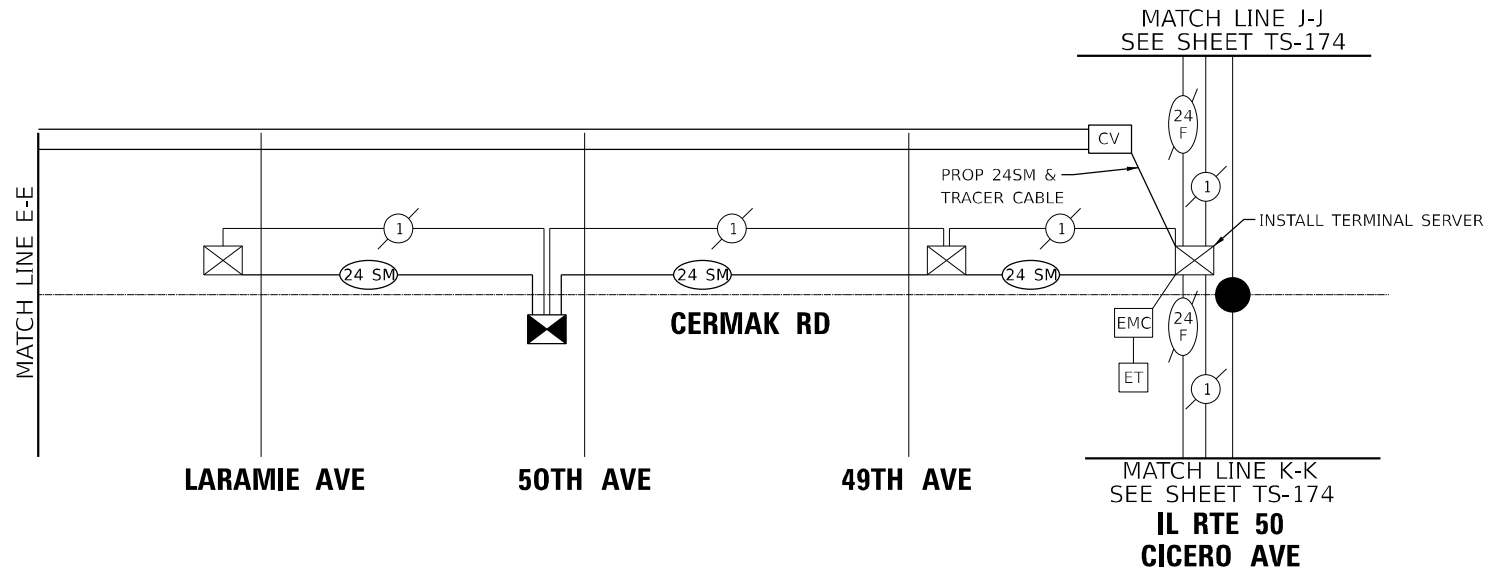

MODEL: \$MODELNAME\$  
FILE NAME: D162N39-sht-TS171-INTERCONNECT.dgn



| F.A.<br>RTE. | SECTION               | COUNTY                    | TOTAL<br>SHEETS | SHEET<br>NO. |
|--------------|-----------------------|---------------------------|-----------------|--------------|
| 771          | 2020-266-SUR, SW & TS | COOK, DUPAGE              | 492             | 320          |
|              |                       | CONTRACT NO. 62N39        |                 |              |
|              |                       | ILLINOIS FED. AID PROJECT |                 |              |



AMES Engineering, Inc.  
CONSULTING ENGINEERS  
6330 Belmont Road, Suite 4B  
Downers Grove, IL 60516

|            |              |          |   |                |         |   |
|------------|--------------|----------|---|----------------|---------|---|
| USER NAME  | = msomer     | DESIGNED | - | WBS, MA        | REVISED | - |
|            |              | DRAWN    | - | MS, MA, MD, SR | REVISED | - |
| PLOT SCALE | = \$SCALE\$  | CHECKED  | - | JWA, AS        | REVISED | - |
| PLOT DATE  | = 03/19/2025 | DATE     | - | 11/08/2024     | REVISED | - |


STATE OF ILLINOIS  
DEPARTMENT OF TRANSPORTATION

INTERCONNECT SCHEMATIC  
CERMAK ROAD

SCALE: NTS    SHEET 1 OF 1 SHEETS    STA.    TO STA.

FOR INFORMATION ONLY

| F.A. RTE.                 | SECTION               | COUNTY       | TOTAL SHEETS | SHEET NO. |
|---------------------------|-----------------------|--------------|--------------|-----------|
| 771                       | 2020-266-SUR, SW & TS | COOK, DUPAGE | 482          | 322       |
| CONTRACT NO. 62N39        |                       |              |              |           |
| ILLINOIS FED. AID PROJECT |                       |              |              |           |

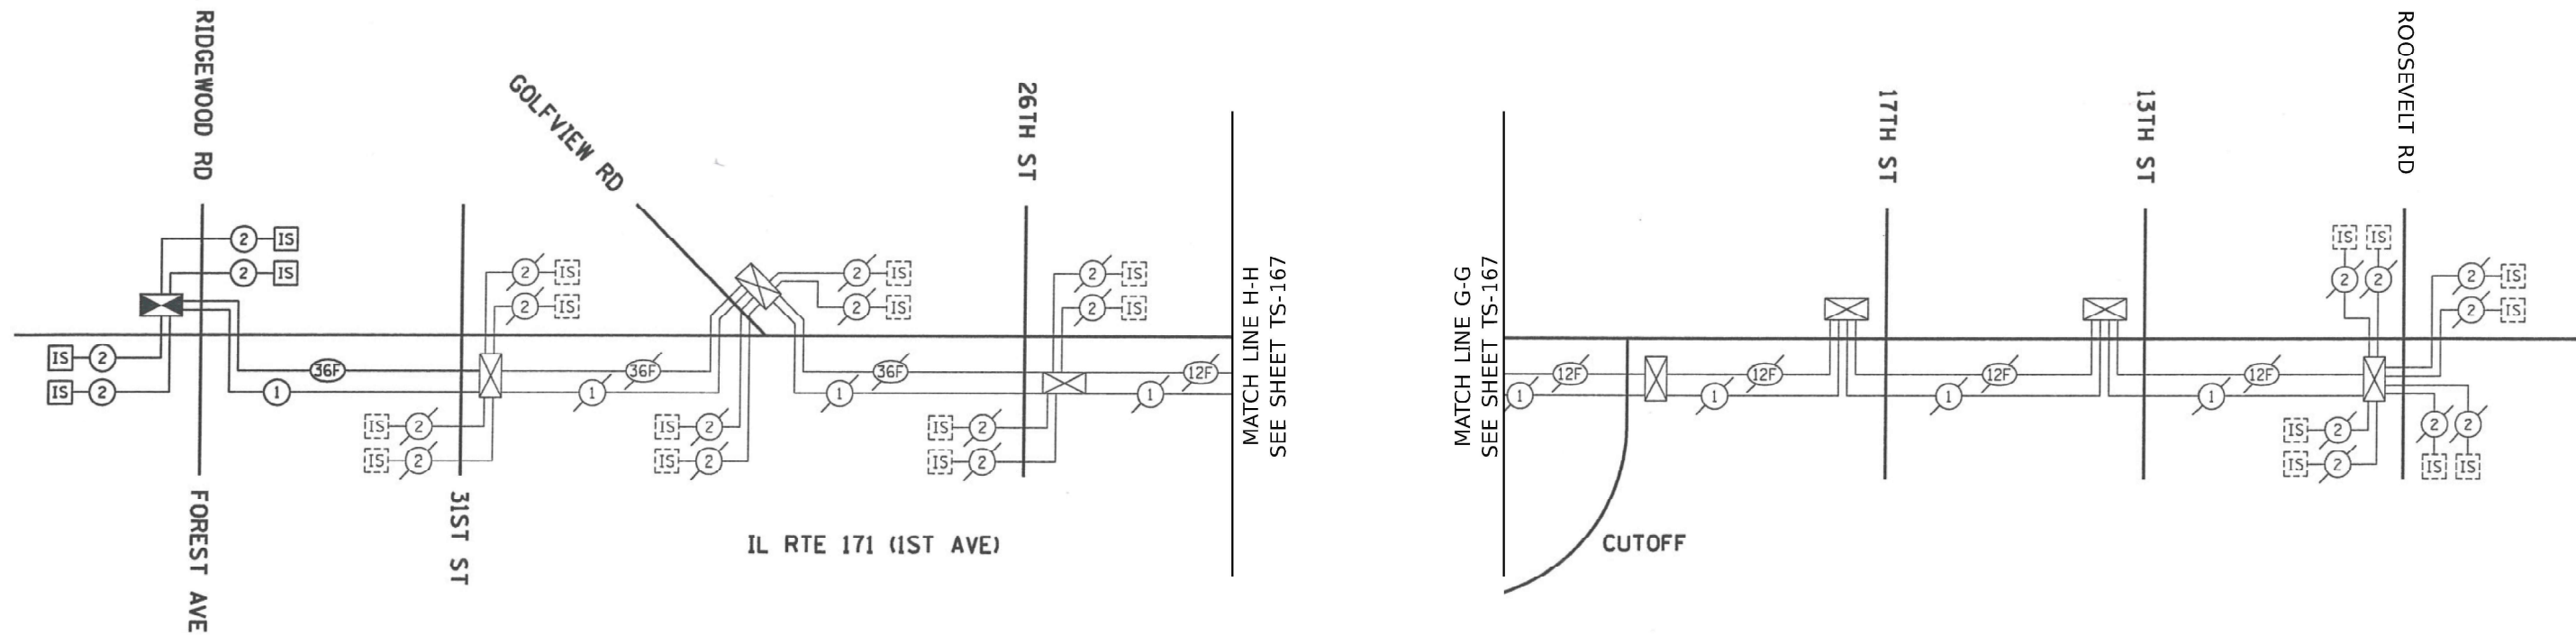



|            |              |          |                   |         |   |
|------------|--------------|----------|-------------------|---------|---|
| USER NAME  | = msomer     | DESIGNED | - TMS, MA         | REVISED | - |
|            |              | DRAWN    | - SPS, MA, MD, SR | REVISED | - |
| PLOT SCALE | = \$SCALE\$  | CHECKED  | - TMR, AS         | REVISED | - |
| PLOT DATE  | = 03/19/2025 | DATE     | - 11/08/2024      | REVISED | - |


STATE OF ILLINOIS  
DEPARTMENT OF TRANSPORTATION

INTERCONNECT SCHEMATIC  
CERMAK ROAD

SCALE: NTS SHEET 1 OF 1 SHEETS STA. TO STA.

FOR INFORMATION ONLY

| F.A. RTE.                 | SECTION               | COUNTY       | TOTAL SHEETS | SHEET NO. |
|---------------------------|-----------------------|--------------|--------------|-----------|
| 771                       | 2020-266-SUR, SW & TS | COOK, DUPAGE | 492          | 323       |
| CONTRACT NO. 62N39        |                       |              |              |           |
| ILLINOIS FED. AID PROJECT |                       |              |              |           |

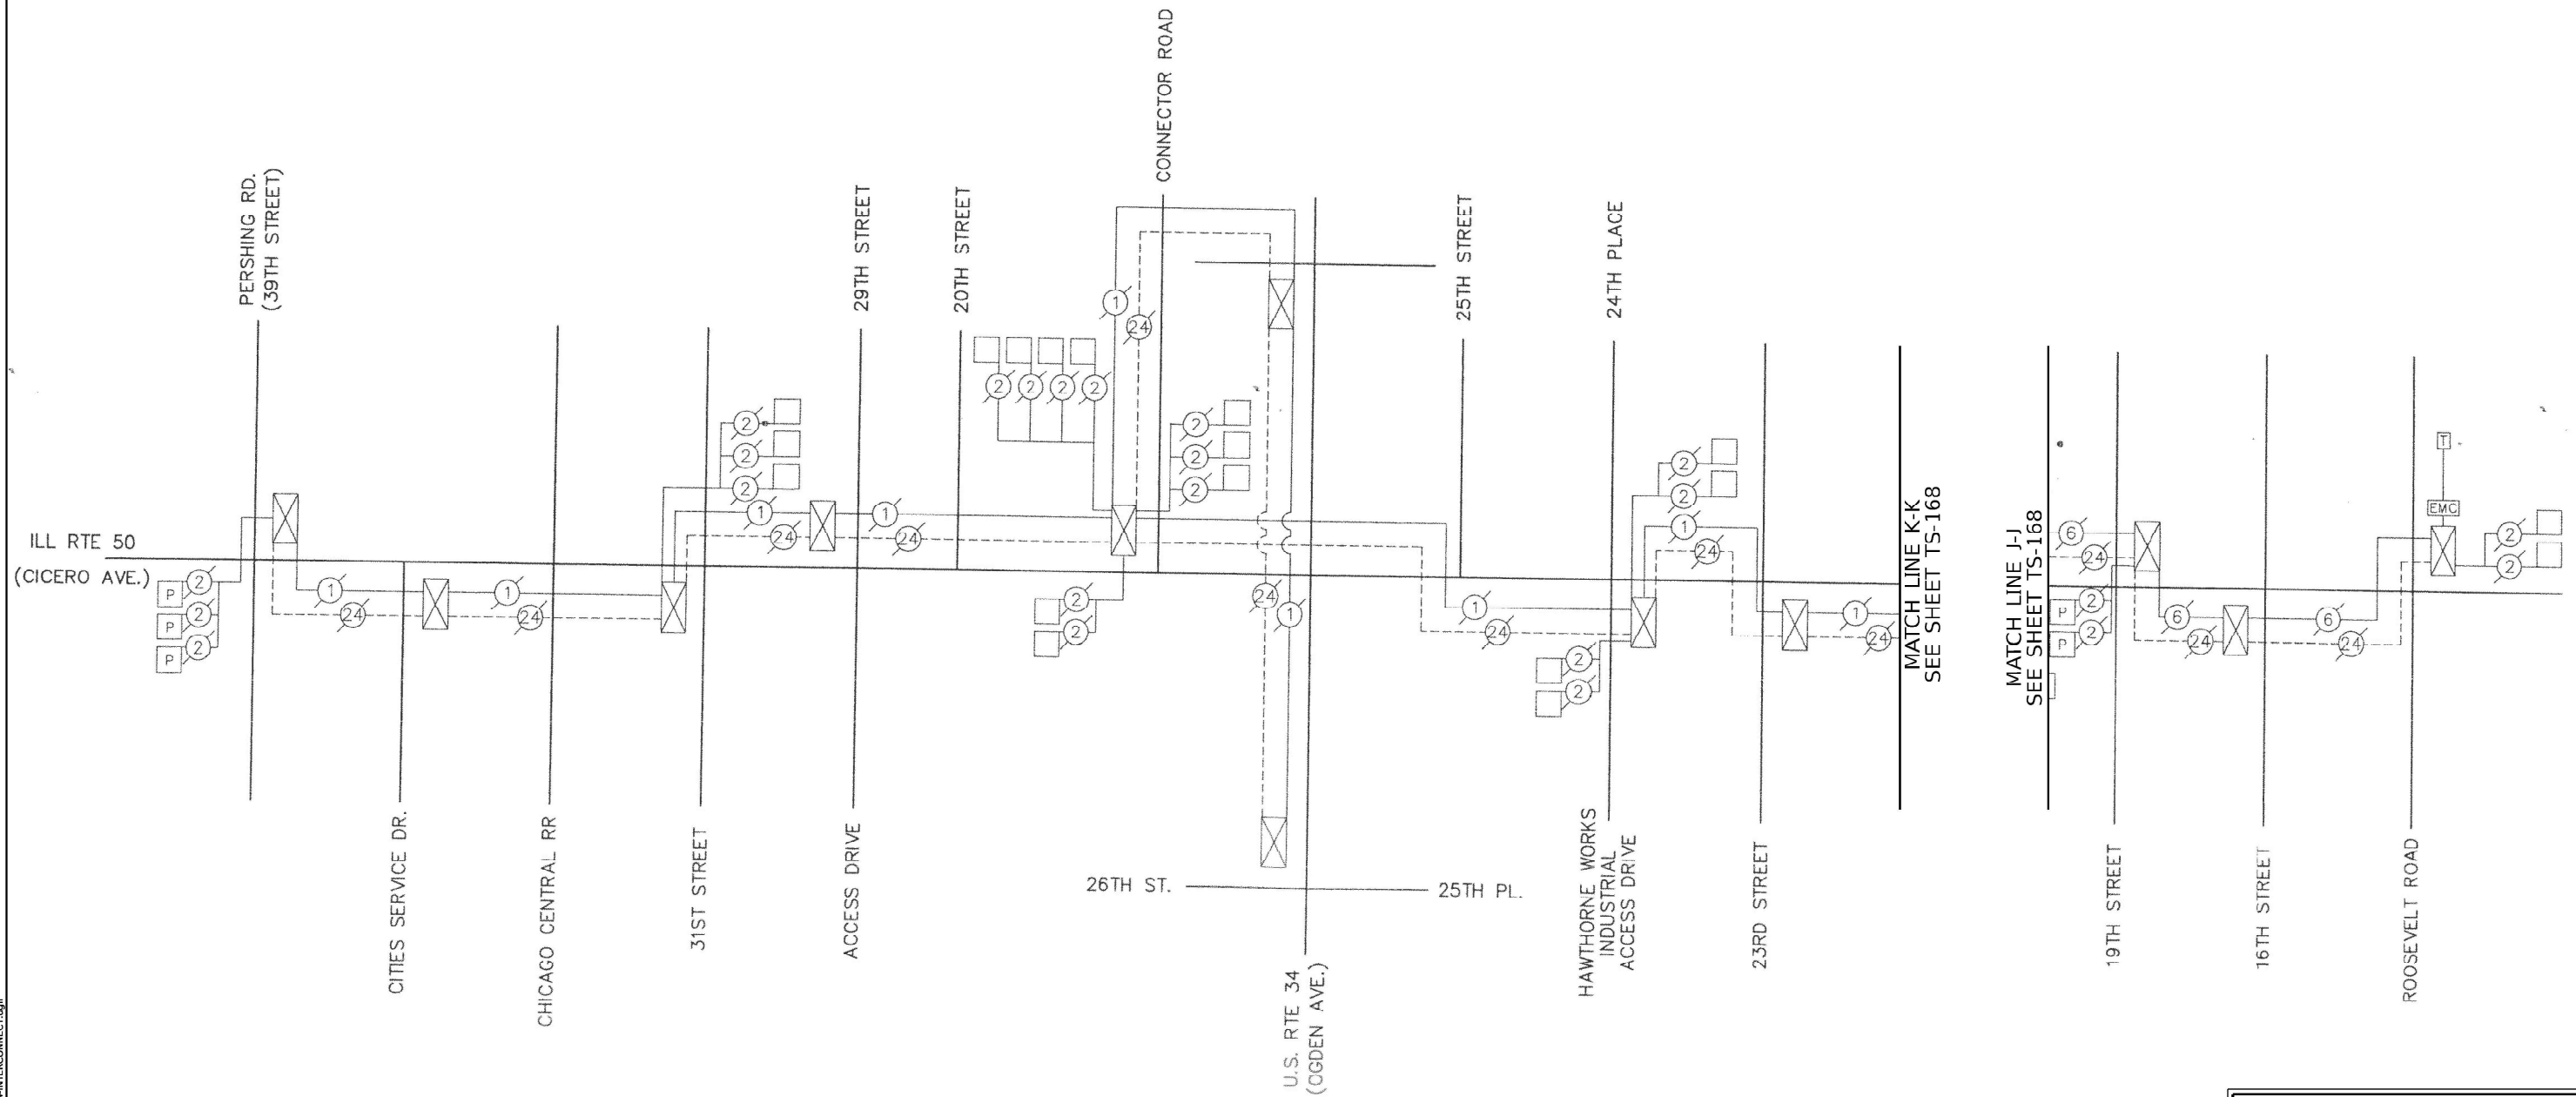





|            |              |
|------------|--------------|
| USER NAME  | = msomer     |
| PLOT SCALE | = \$SCALE\$  |
| PLOT DATE  | = 03/19/2025 |

|          |              |
|----------|--------------|
| DESIGNED | - TM         |
| DRAWN    | - TM, SR     |
| CHECKED  | - JAR        |
| DATE     | - 05/23/2024 |

|         |   |
|---------|---|
| REVISED | - |
| REVISED | - |
| REVISED | - |
| REVISED | - |

STATE OF ILLINOIS  
DEPARTMENT OF TRANSPORTATION


|                                                              |          |         |           |
|--------------------------------------------------------------|----------|---------|-----------|
| BLUETOOTH INSTALLATION PLAN<br>CERMAK RD AND I-294 WEST RAMP |          |         |           |
| SCALE:                                                       | 1" = 20' | SHEET   | OF SHEETS |
| STA.                                                         |          | TO STA. |           |

|                           |                       |             |              |           |
|---------------------------|-----------------------|-------------|--------------|-----------|
| F.A.U. RTE.               | SECTION               | COUNTY      | TOTAL SHEETS | SHEET NO. |
| 1453                      | 2020-266-SUR, SW & TS | COOK/DUPAGE | 492          | 324       |
| CONTRACT NO. 62N39        |                       |             |              |           |
| ILLINOIS FED. AID PROJECT |                       |             |              |           |

TS 135  
IDOT CENTRACS  
FORMER ECON 101

SCHEDULE OF QUANTITIES

| ITEM DESCRIPTION                              | UNITS | TOTAL QTY. |
|-----------------------------------------------|-------|------------|
| TRAFFIC SIGNAL POST, GALVANIZED STEEL, 16 FT. | EACH  | 1          |
| CONCRETE FOUNDATION, TYPE A                   | FOOT  | 4          |
| BLUETOOTH DETECTOR                            | EACH  | 1          |

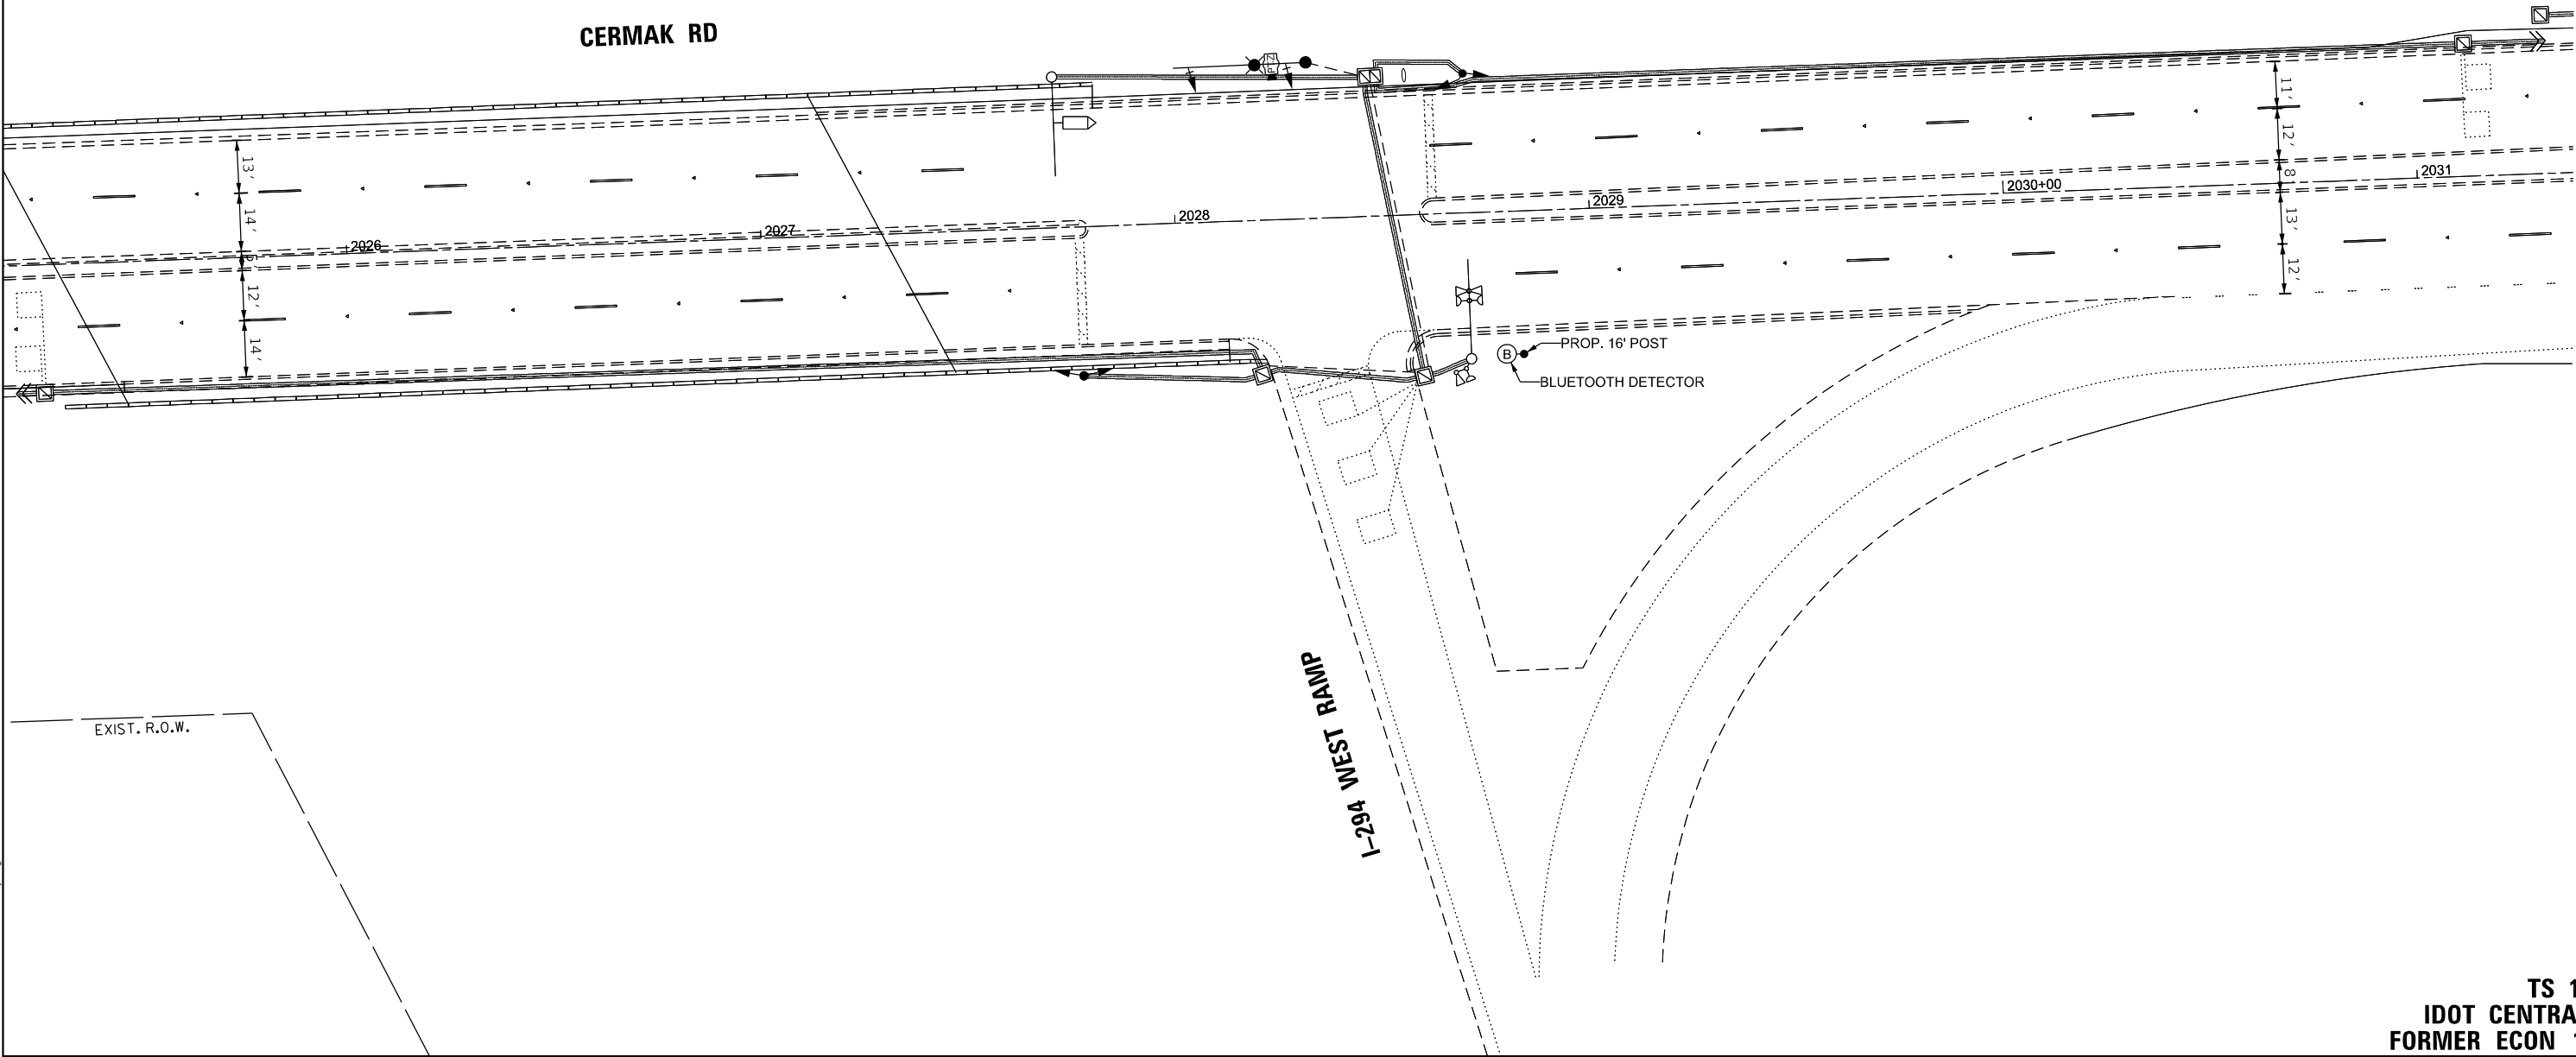

TS SHT NO. 176

MODEL NAME: 62N39-176  
FILE NAME: 62N39-176.BIT I-294 East Ramps.dgn



|            |              |
|------------|--------------|
| USER NAME  | = msomer     |
| PLOT SCALE | = \$SCALE\$  |
| PLOT DATE  | = 03/19/2025 |

|          |              |
|----------|--------------|
| DESIGNED | - TM         |
| DRAWN    | - TM, SR     |
| CHECKED  | - JAR        |
| DATE     | - 05/23/2024 |

|         |   |
|---------|---|
| REVISED | - |
| REVISED | - |
| REVISED | - |
| REVISED | - |


STATE OF ILLINOIS  
DEPARTMENT OF TRANSPORTATION

SCALE: 1" = 20' SHEET OF SHEETS STA. TO STA.

BLUETOOTH INSTALLATION PLAN  
CERMAK RD AND I-294 EAST RAMP

| F.A.U. RTE.               | SECTION               | COUNTY      | TOTAL SHEETS | SHEET NO. |
|---------------------------|-----------------------|-------------|--------------|-----------|
| 1453                      | 2020-266-SUR, SW & TS | COOK/DUPAGE | 492          | 325       |
| CONTRACT NO. 62N39        |                       |             |              |           |
| ILLINOIS FED. AID PROJECT |                       |             |              |           |

TS 130  
IDOT CENTRACS  
FORMER ECON 101

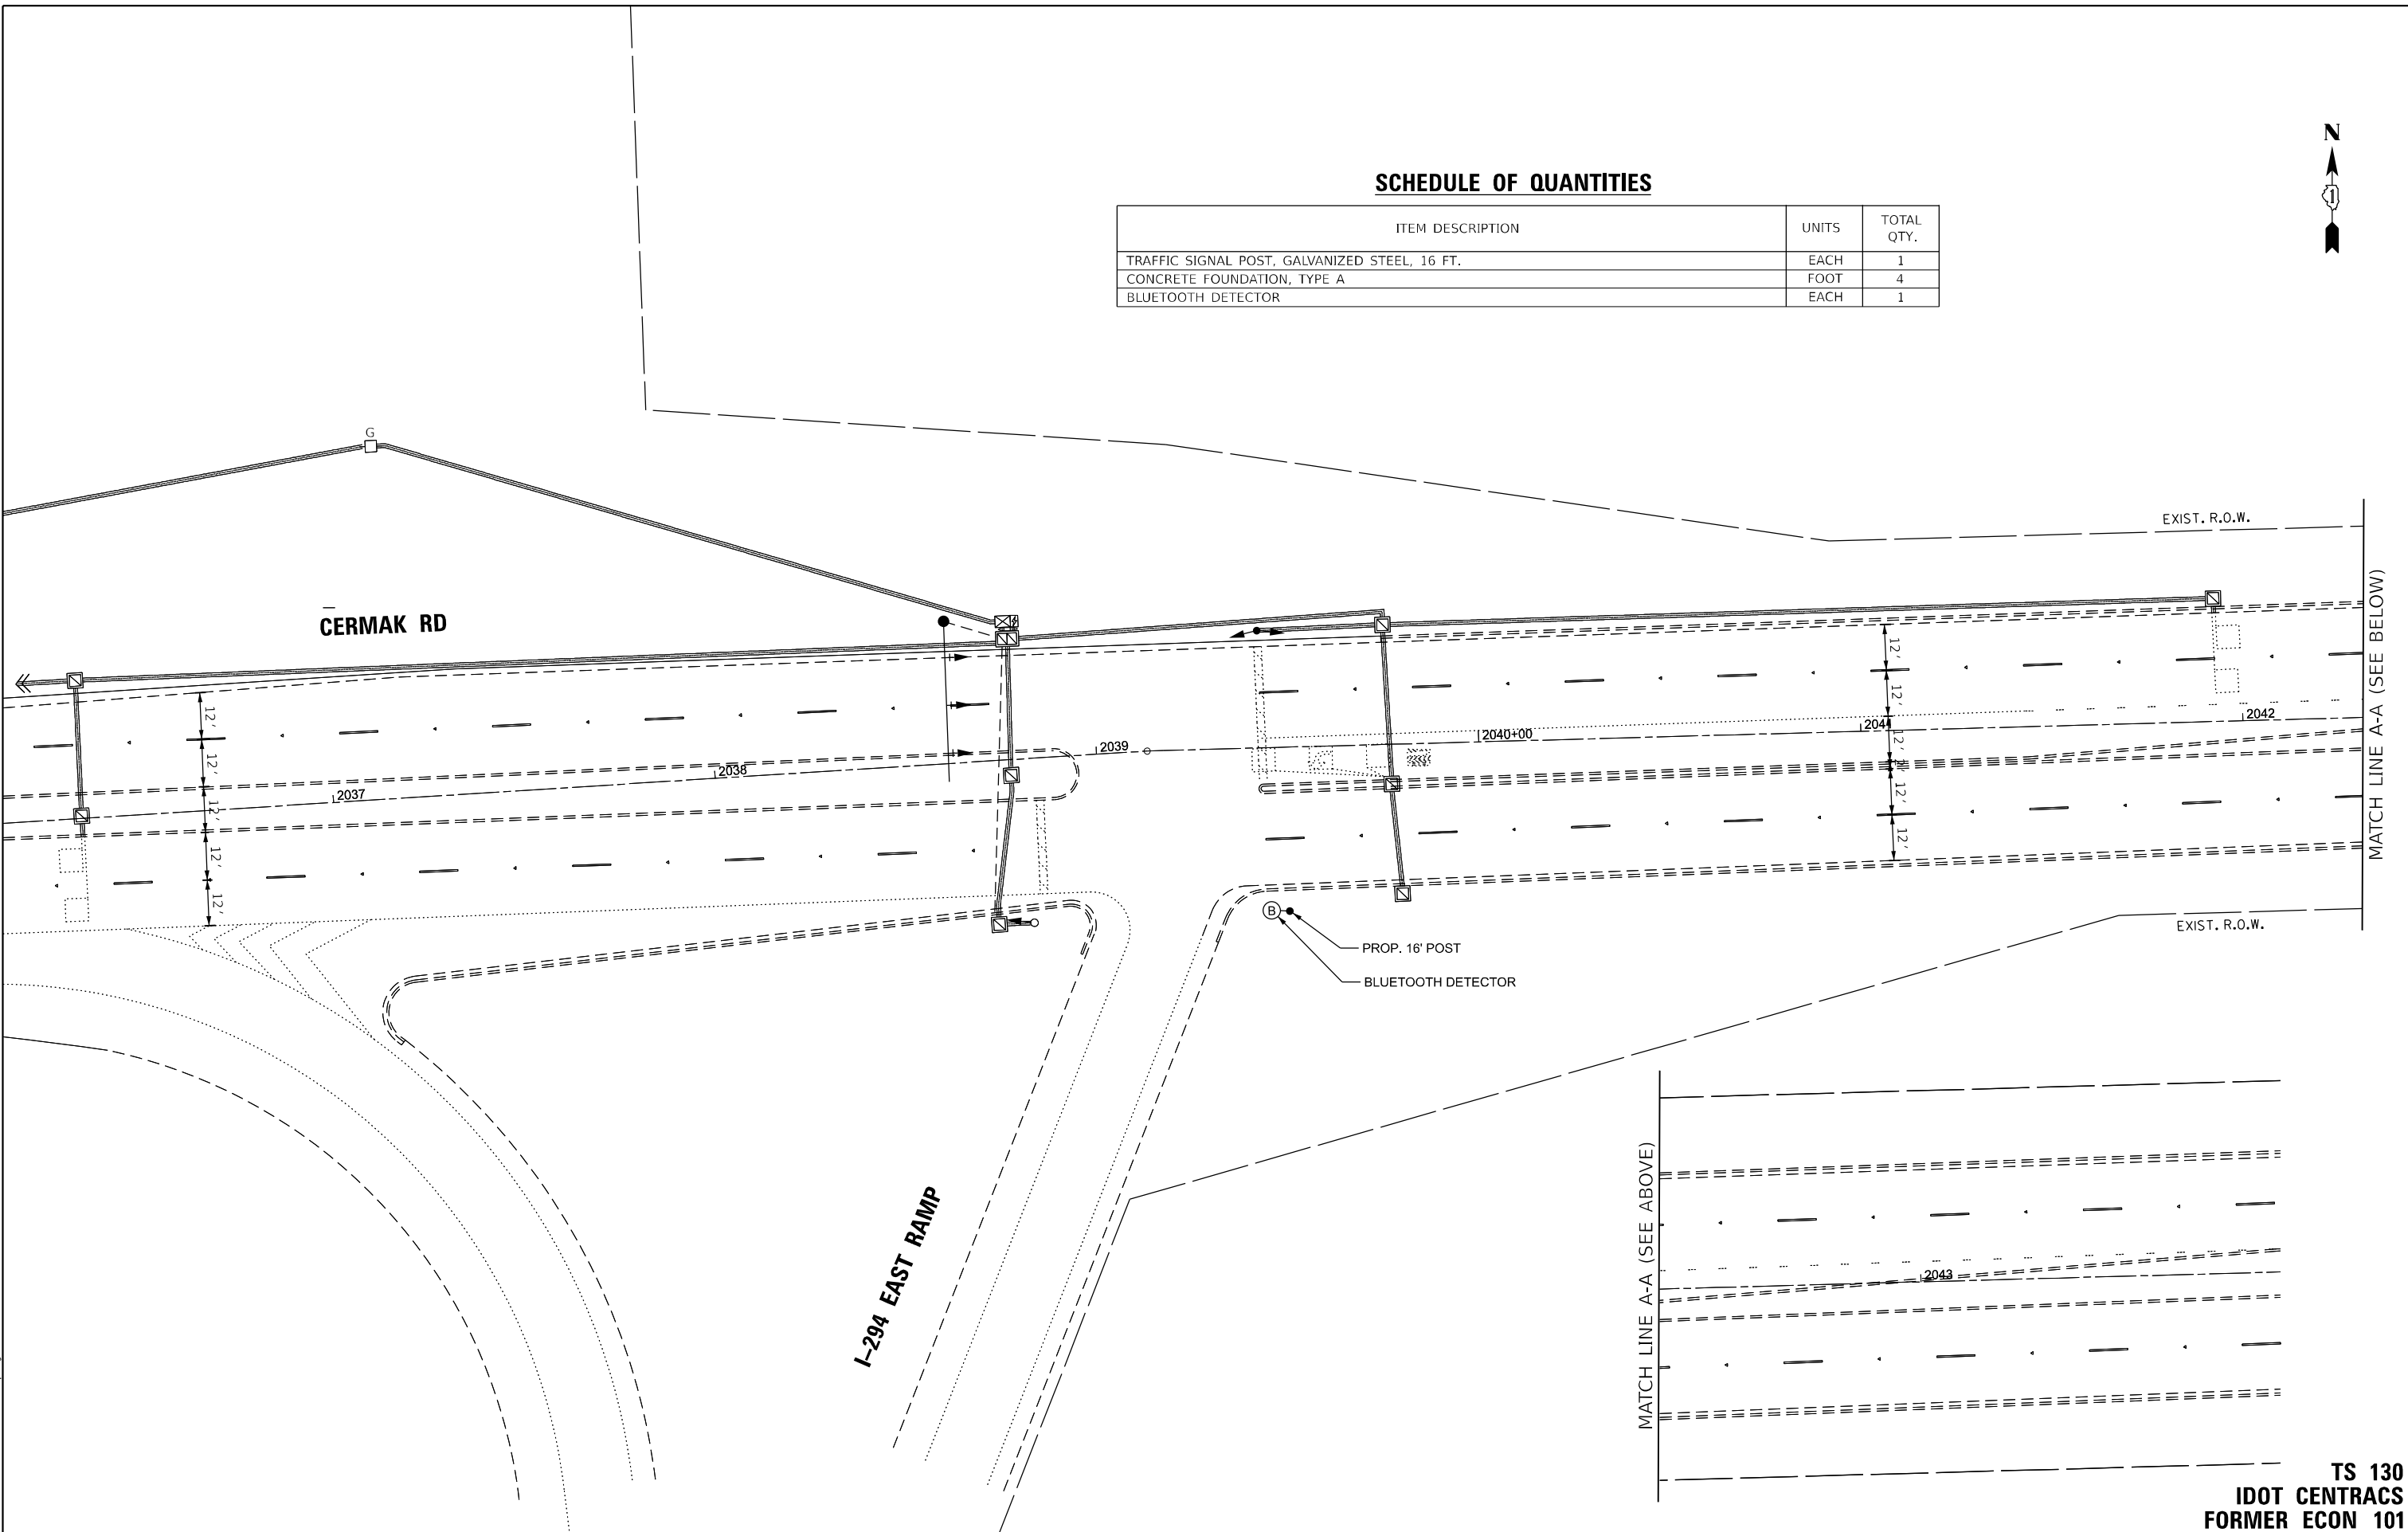


SCHEDULE OF QUANTITIES

| ITEM DESCRIPTION                              | UNITS | TOTAL QTY. |
|-----------------------------------------------|-------|------------|
| TRAFFIC SIGNAL POST, GALVANIZED STEEL, 16 FT. | EACH  | 1          |
| CONCRETE FOUNDATION, TYPE A                   | FOOT  | 4          |
| BLUETOOTH DETECTOR                            | EACH  | 1          |



SCHEDULE OF QUANTITIES

| ITEM DESCRIPTION                              | UNITS | TOTAL QTY. |
|-----------------------------------------------|-------|------------|
| TRAFFIC SIGNAL POST, GALVANIZED STEEL, 16 FT. | EACH  | 1          |
| CONCRETE FOUNDATION, TYPE A                   | FOOT  | 4          |
| BLUETOOTH DETECTOR                            | EACH  | 1          |

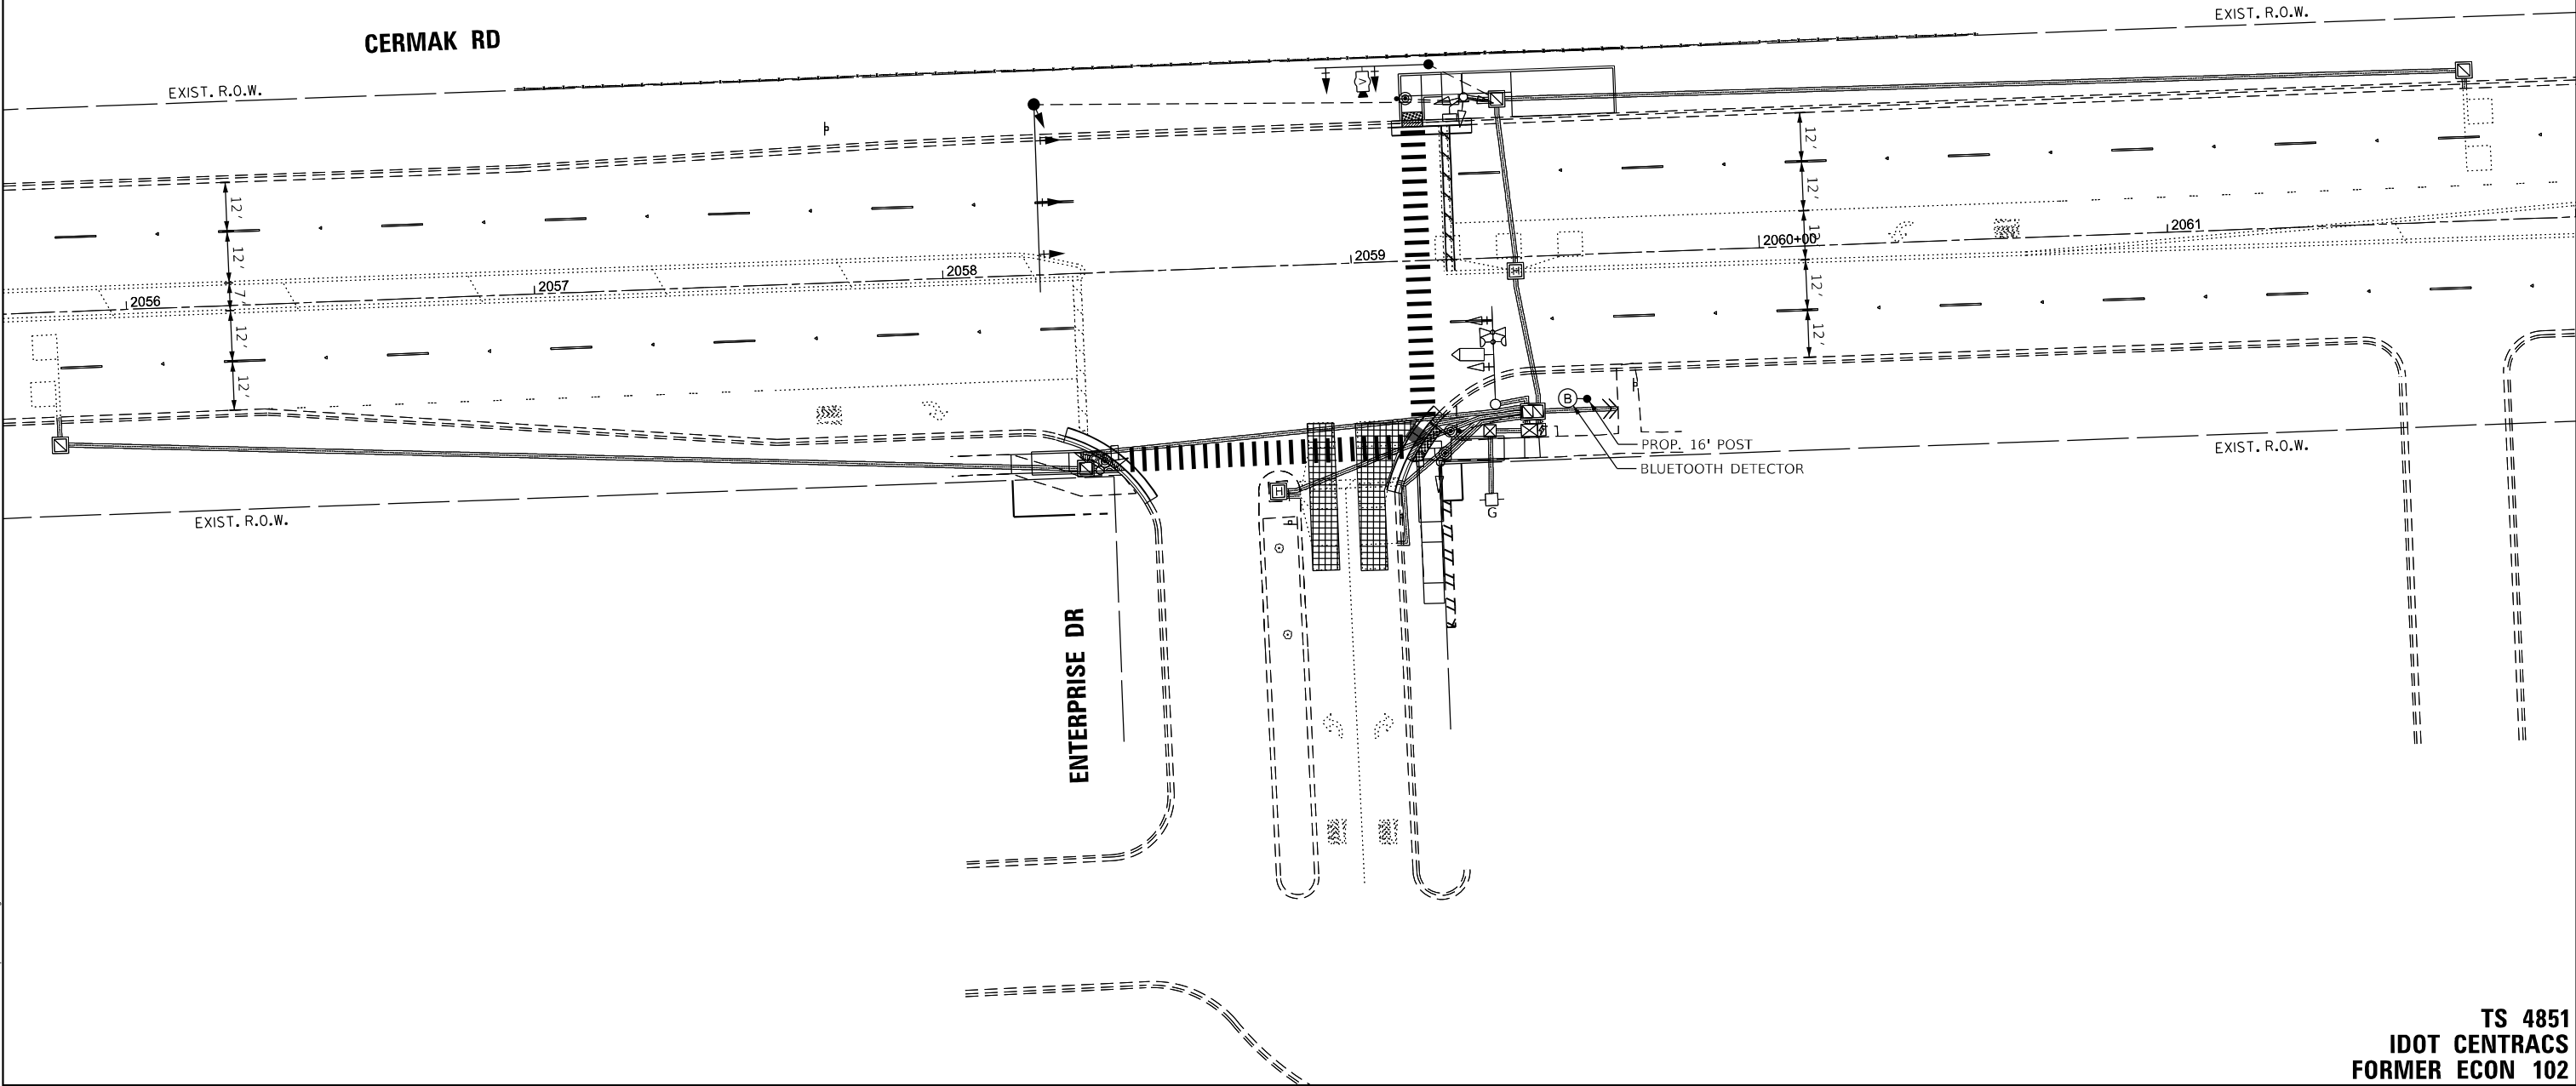

TS SHT NO. 177

MODEL NAME: 62N39-266-SUR-TS177-Bluetooth.dgn  
FILE NAME: 62N39-266-SUR-TS177-Bluetooth.dgn

AMES Engineering, Inc.  
CONSULTING ENGINEERS  
6330 Belmont Road, Suite 4B  
Downers Grove, IL 60516

|                        |                   |           |
|------------------------|-------------------|-----------|
| USER NAME = msomer     | DESIGNED - TM     | REVISED - |
|                        | DRAWN - TM, SR    | REVISED - |
| PLOT SCALE = \$SCALE\$ | CHECKED - JAR     | REVISED - |
| PLOT DATE = 03/19/2025 | DATE - 05/23/2024 | REVISED - |

STATE OF ILLINOIS  
DEPARTMENT OF TRANSPORTATION

BLUETOOTH INSTALLATION PLAN  
CERMAK RD AND ENTERPRISE DR

SCALE: 1" = 20' SHEET OF SHEETS STA. TO STA.

| F.A.U. RTE.               | SECTION               | COUNTY      | TOTAL SHEETS | SHEET NO. |
|---------------------------|-----------------------|-------------|--------------|-----------|
| 1453                      | 2020-266-SUR, SW & TS | COOK/DUPAGE | 492          | 326       |
| CONTRACT NO. 62N39        |                       |             |              |           |
| ILLINOIS FED. AID PROJECT |                       |             |              |           |

TS 4851  
IDOT CENTRACS  
FORMER ECON 102

|            |              |
|------------|--------------|
| USER NAME  | = msomer     |
| PLOT SCALE | = \$SCALE\$  |
| PLOT DATE  | = 03/19/2025 |

|          |              |
|----------|--------------|
| DESIGNED | - TM         |
| DRAWN    | - TM, SR     |
| CHECKED  | - JAR        |
| DATE     | - 05/23/2024 |


|         |   |
|---------|---|
| REVISED | - |
| REVISED | - |
| REVISED | - |
| REVISED | - |

STATE OF ILLINOIS  
DEPARTMENT OF TRANSPORTATION

BLUETOOTH INSTALLATION PLAN  
CERMAK RD AND WOLF RD

SCALE: 1" = 20' SHEET OF SHEETS STA. TO STA.

| F.A.U. RTE.               | SECTION               | COUNTY      | TOTAL SHEETS | SHEET NO. |
|---------------------------|-----------------------|-------------|--------------|-----------|
| 1453                      | 2020-266-SUR, SW & TS | COOK/DUPAGE | 492          | 327       |
| CONTRACT NO. 62N39        |                       |             |              |           |
| ILLINOIS FED. AID PROJECT |                       |             |              |           |

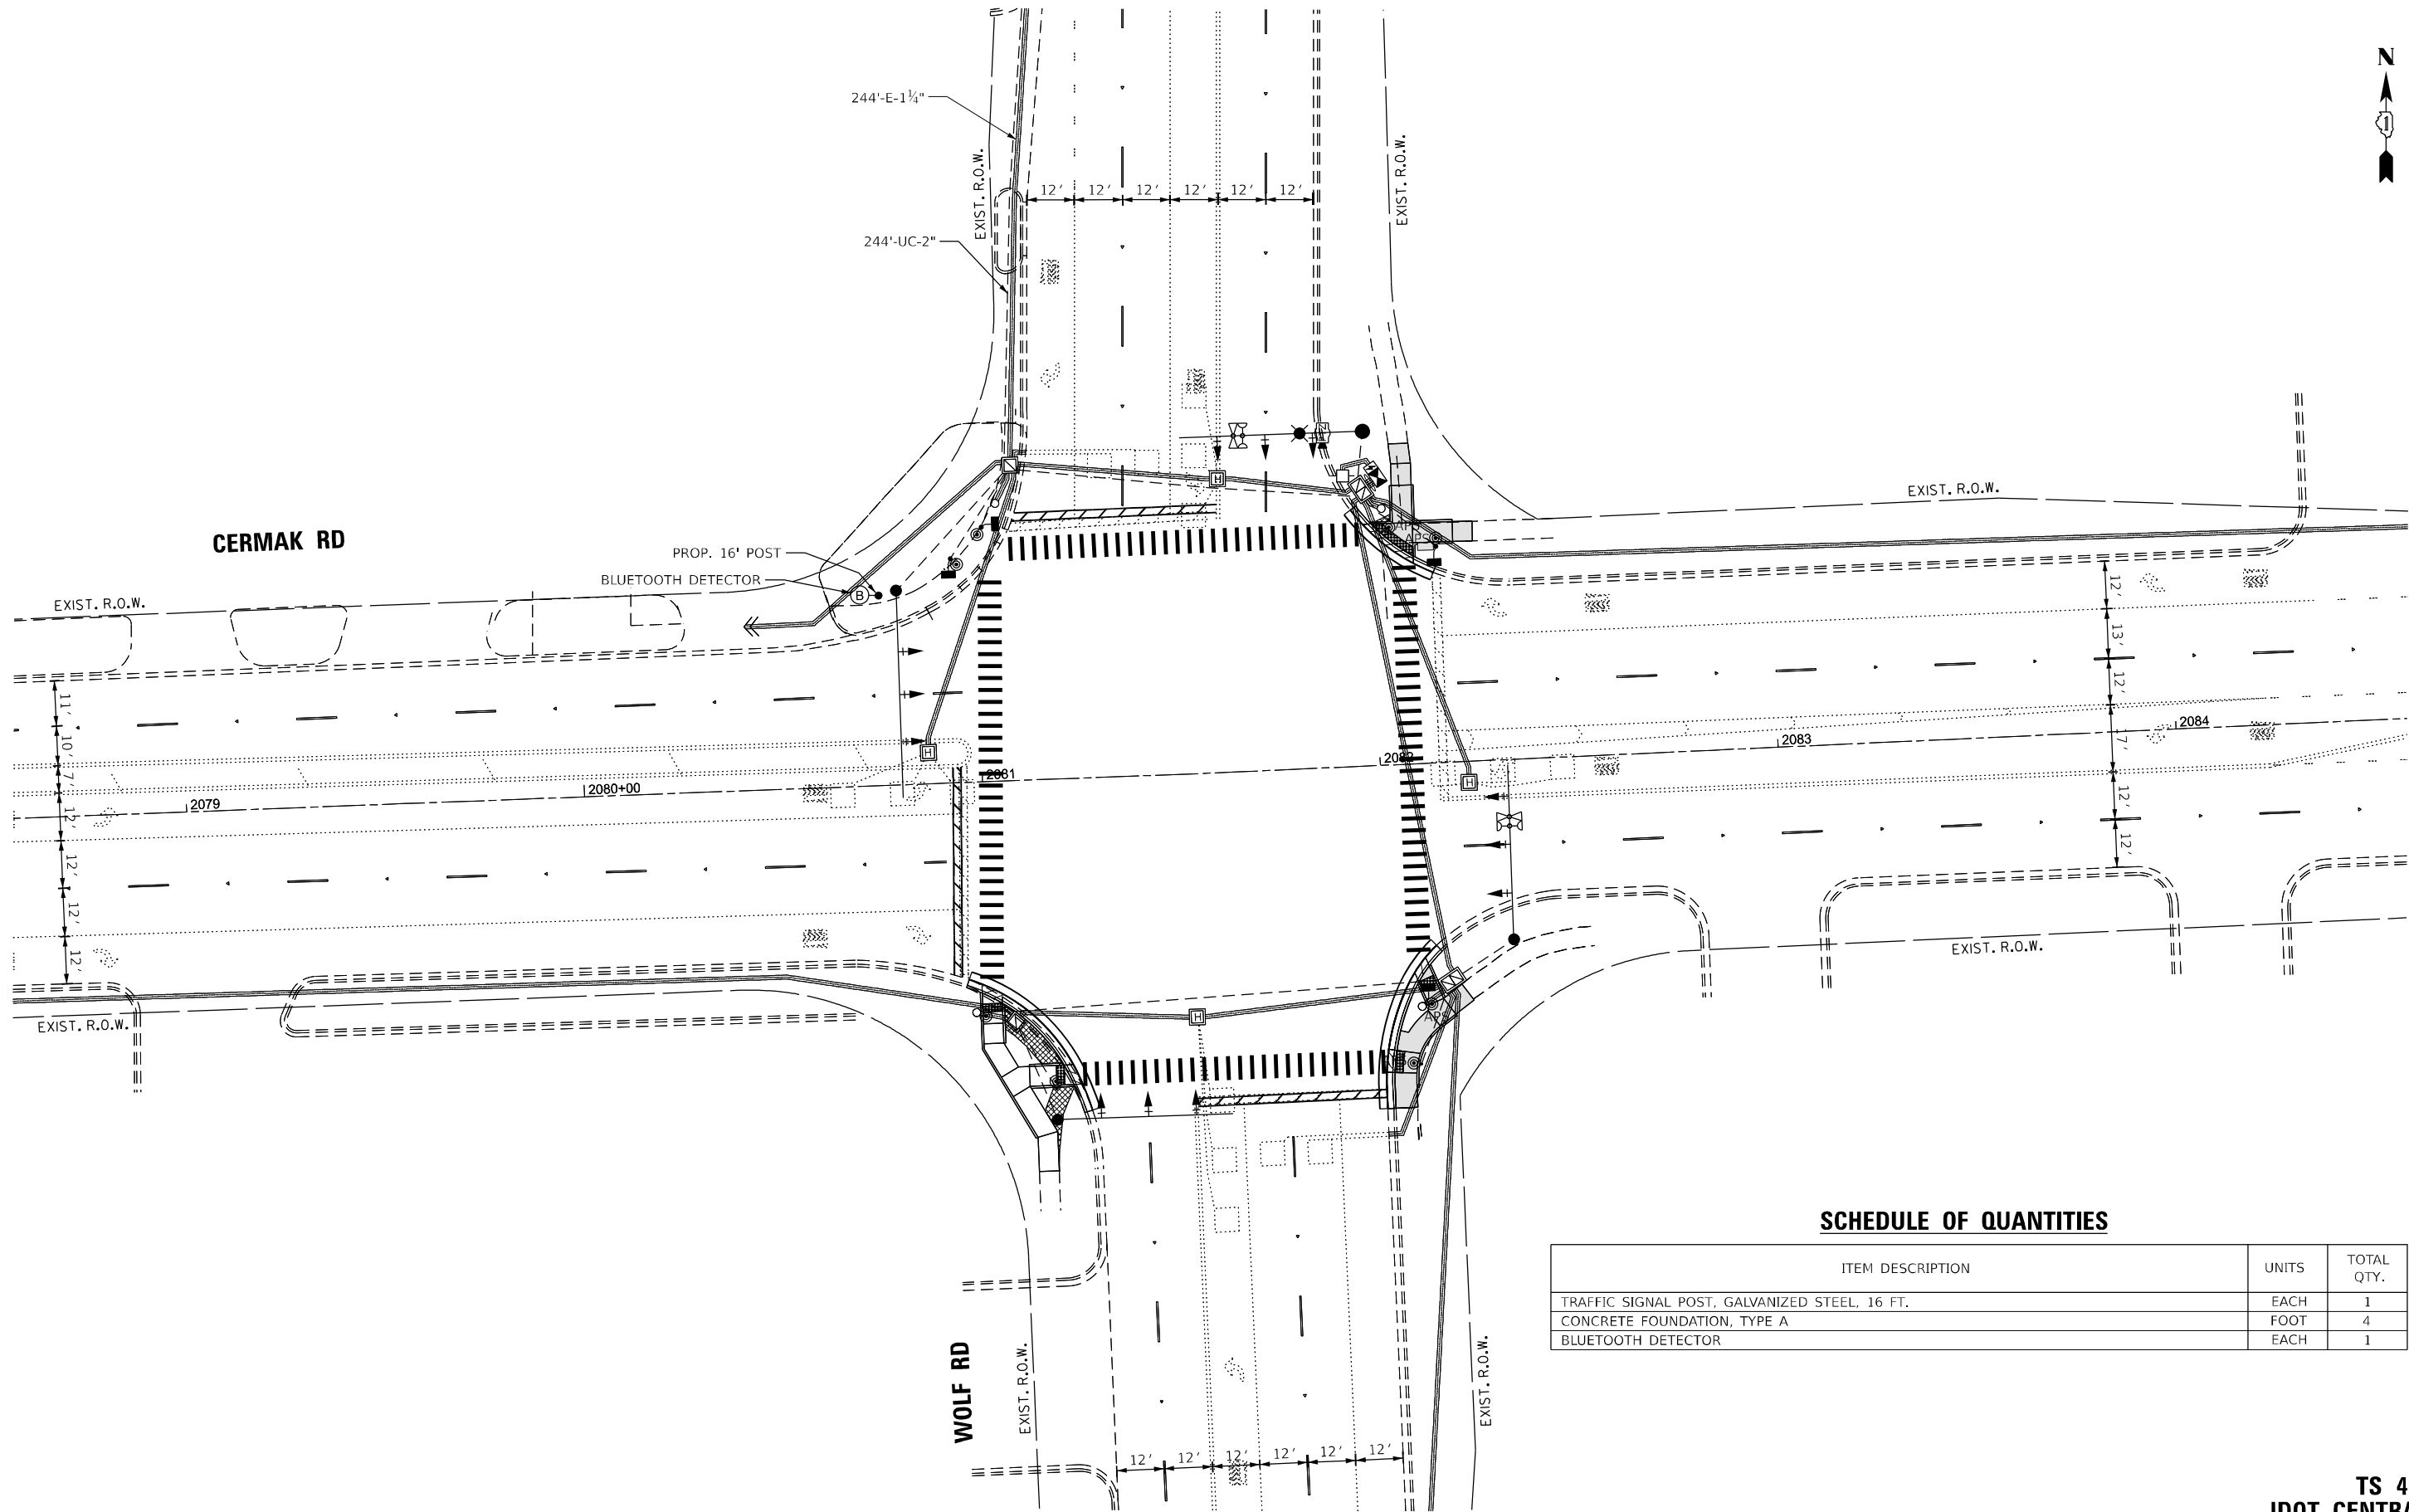

SCHEDULE OF QUANTITIES

| ITEM DESCRIPTION                              | UNITS | TOTAL QTY. |
|-----------------------------------------------|-------|------------|
| TRAFFIC SIGNAL POST, GALVANIZED STEEL, 16 FT. | EACH  | 1          |
| CONCRETE FOUNDATION, TYPE A                   | FOOT  | 4          |
| BLUETOOTH DETECTOR                            | EACH  | 1          |



|            |              |
|------------|--------------|
| USER NAME  | = msomer     |
| PLOT SCALE | = \$SCALE\$  |
| PLOT DATE  | = 03/19/2025 |

|          |   |            |
|----------|---|------------|
| DESIGNED | - | TM         |
| DRAWN    | - | TM, SR     |
| CHECKED  | - | JAR        |
| DATE     | - | 05/23/2024 |

|         |   |
|---------|---|
| REVISED | - |
| REVISED | - |
| REVISED | - |
| REVISED | - |


STATE OF ILLINOIS  
DEPARTMENT OF TRANSPORTATION

BLUETOOTH INSTALLATION PLAN  
CERMAK RD AND MAYFAIR AVE

SCALE: 1" = 20' SHEET OF SHEETS STA. TO STA.

| F.A.U. RTE.               | SECTION               | COUNTY      | TOTAL SHEETS | SHEET NO. |
|---------------------------|-----------------------|-------------|--------------|-----------|
| 1453                      | 2020-266-SUR, SW & TS | COOK/DUPAGE | 492          | 328       |
| CONTRACT NO. 62N39        |                       |             |              |           |
| ILLINOIS FED. AID PROJECT |                       |             |              |           |

TS 15115  
IDOT CENTRACS  
FORMER ECON 102

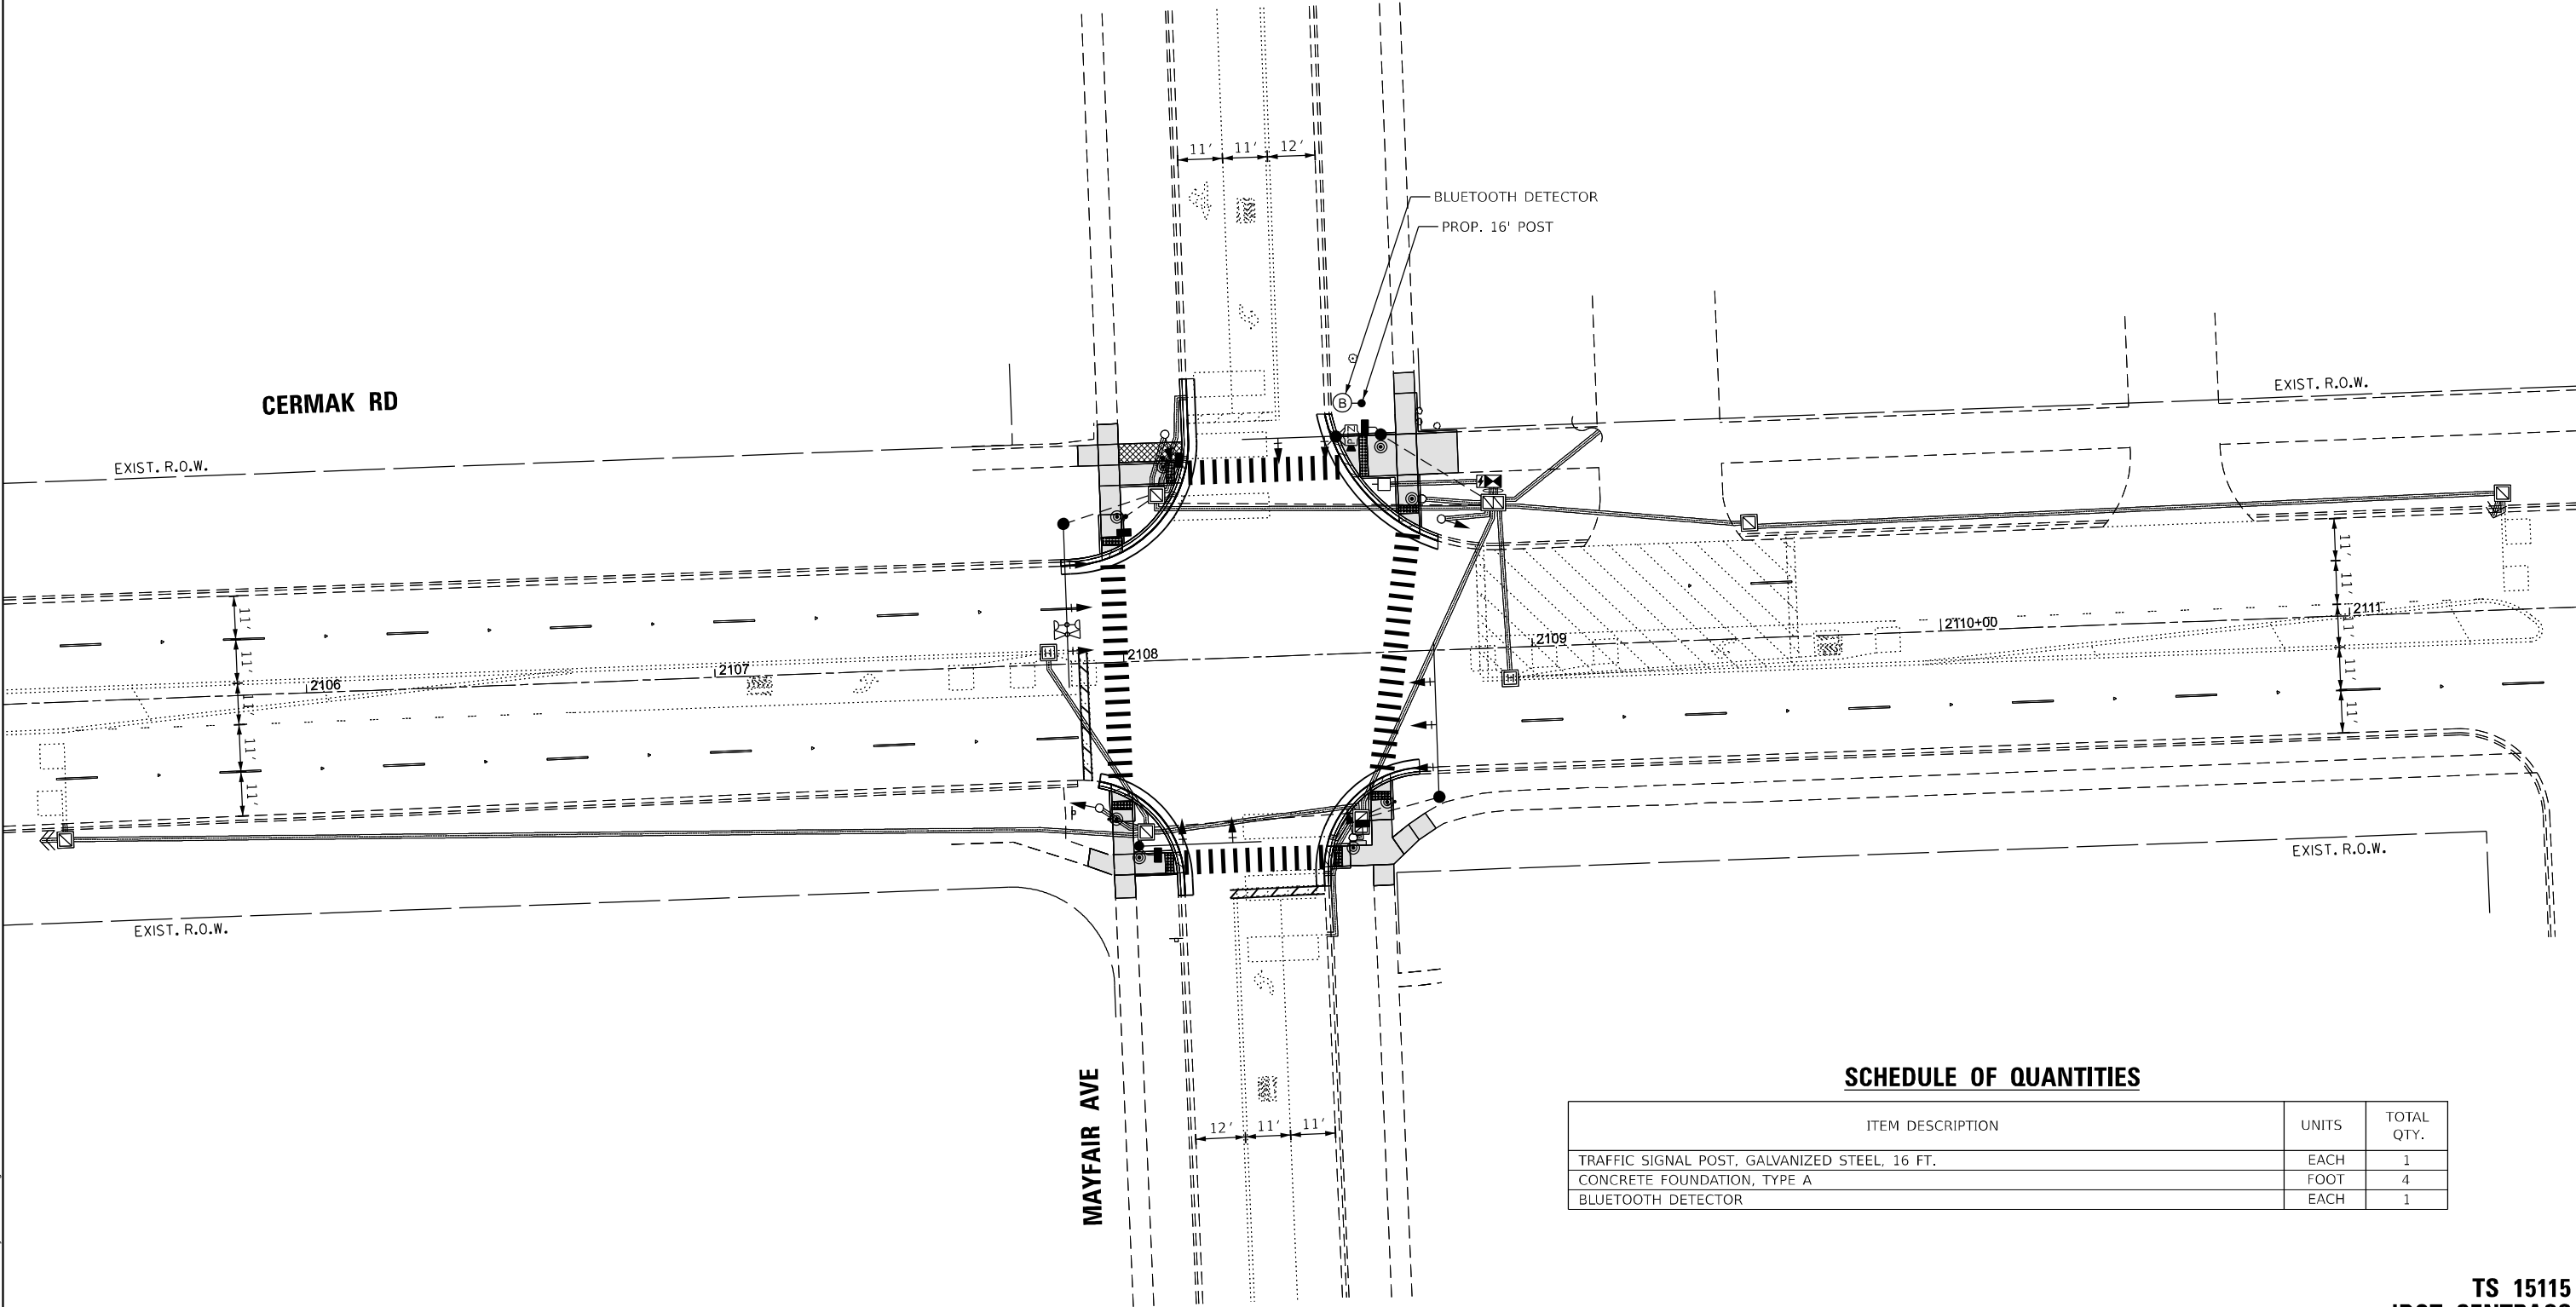

SCHEDULE OF QUANTITIES

| ITEM DESCRIPTION                              | UNITS | TOTAL QTY. |
|-----------------------------------------------|-------|------------|
| TRAFFIC SIGNAL POST, GALVANIZED STEEL, 16 FT. | EACH  | 1          |
| CONCRETE FOUNDATION, TYPE A                   | FOOT  | 4          |
| BLUETOOTH DETECTOR                            | EACH  | 1          |





USER NAME = msomer  
PLOT SCALE = \$SCALE\$  
PLOT DATE = 03/19/2025

DESIGNED - TM  
DRAWN - TM, SR  
CHECKED - JAR  
DATE - 05/23/2024

REVISED -  
REVISED -  
REVISED -  
REVISED -

STATE OF ILLINOIS  
DEPARTMENT OF TRANSPORTATION

BLUETOOTH INSTALLATION PLAN  
CERMAK RD AND US 12-20-45 (LAGRANGE RD/MANNHEIM RD)


SCALE: 1" = 20' SHEET OF SHEETS STA. TO STA.

| F.A.U. RTE.               | SECTION               | COUNTY      | TOTAL SHEETS | SHEET NO. |
|---------------------------|-----------------------|-------------|--------------|-----------|
| 1453                      | 2020-266-SUR, SW & TS | COOK/DUPAGE | 492          | 329       |
| CONTRACT NO. 62N39        |                       |             |              |           |
| ILLINOIS FED. AID PROJECT |                       |             |              |           |

TS 1050  
IDOT CENTRACS  
FORMER ECON 102


SCHEDULE OF QUANTITIES

| ITEM DESCRIPTION                              | UNITS | TOTAL QTY. |
|-----------------------------------------------|-------|------------|
| TRAFFIC SIGNAL POST, GALVANIZED STEEL, 16 FT. | EACH  | 1          |
| CONCRETE FOUNDATION, TYPE A                   | FOOT  | 4          |
| BLUETOOTH DETECTOR                            | EACH  | 1          |

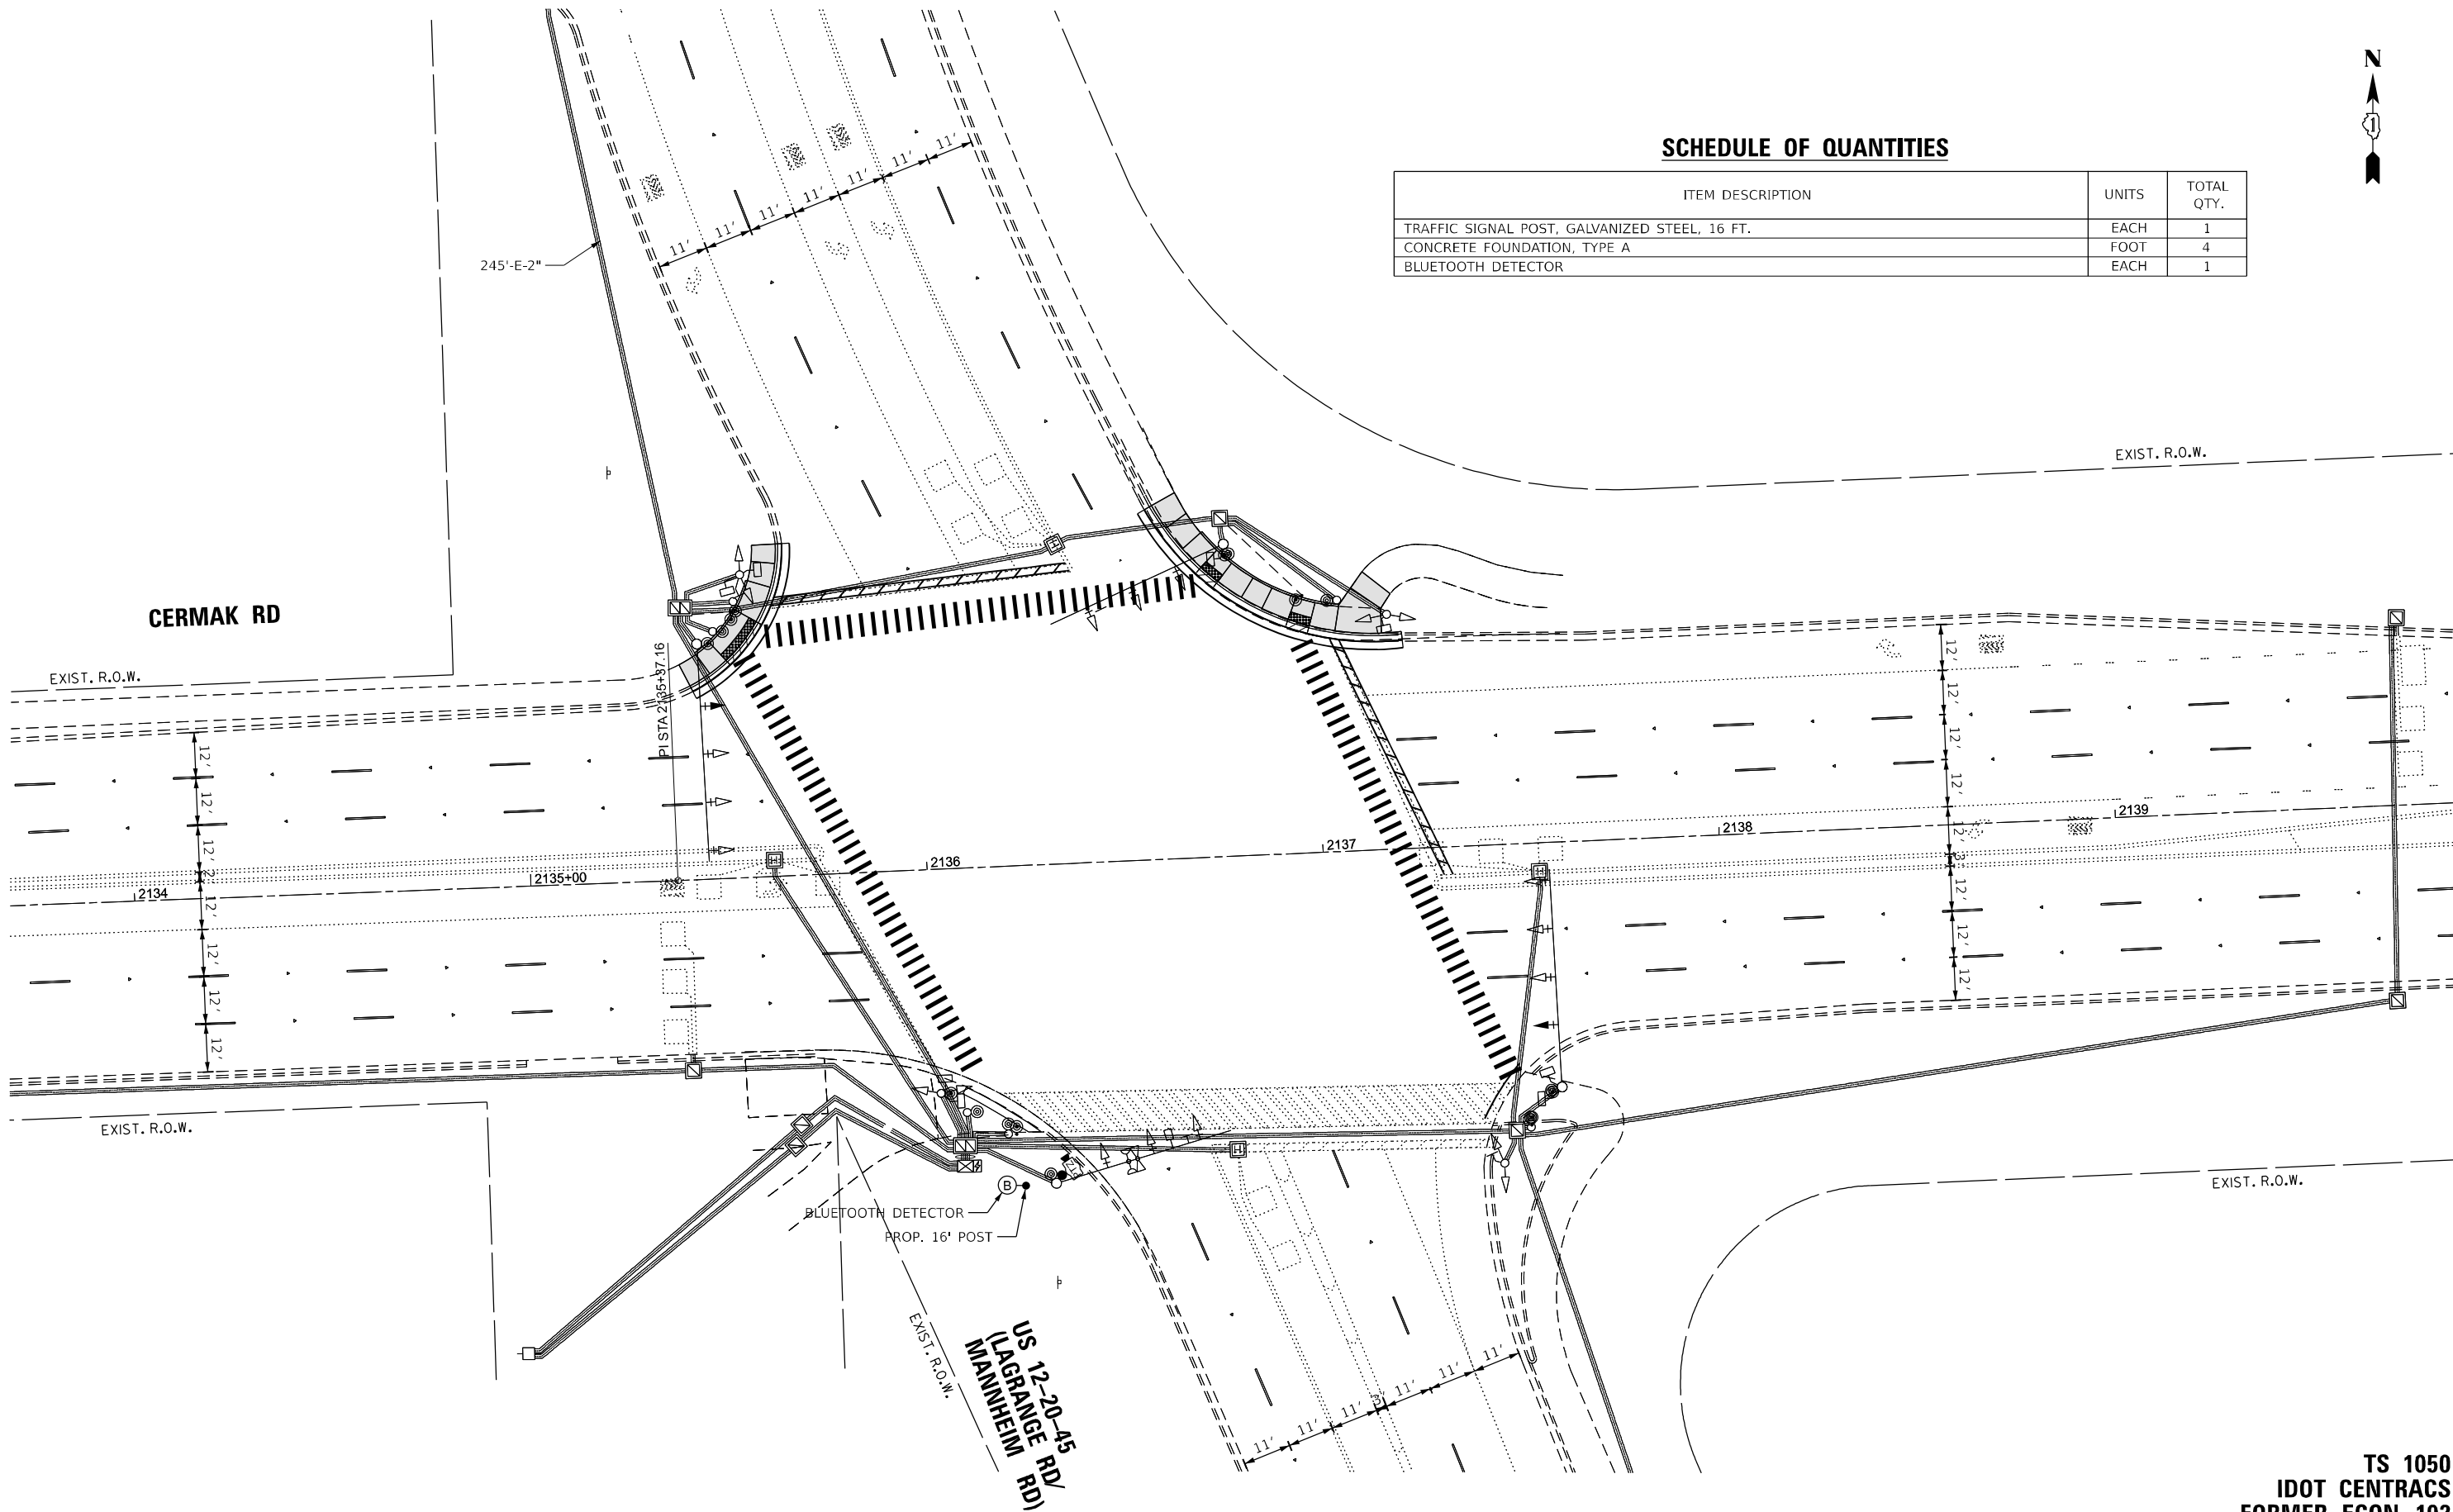

|            |              |            |              |           |  |
|------------|--------------|------------|--------------|-----------|--|
| USER NAME  | = msomer     | DESIGNED - | TM           | REVISED - |  |
|            |              | DRAWN -    | TM, SR       | REVISED - |  |
| PLOT SCALE | = \$SCALE\$  | CHECKED -  | JAR          | REVISED - |  |
| PLOT DATE  | = 03/19/2025 | DATE       | = 05/23/2024 | REVISED - |  |

| F.A.U. RTE.               | SECTION               | COUNTY      | TOTAL SHEETS | SHEET NO. |
|---------------------------|-----------------------|-------------|--------------|-----------|
| 1453                      | 2020-266-SUR, SW & TS | COOK/DUPAGE | 492          | 330       |
| CONTRACT NO. 62N39        |                       |             |              |           |
| ILLINOIS FED. AID PROJECT |                       |             |              |           |

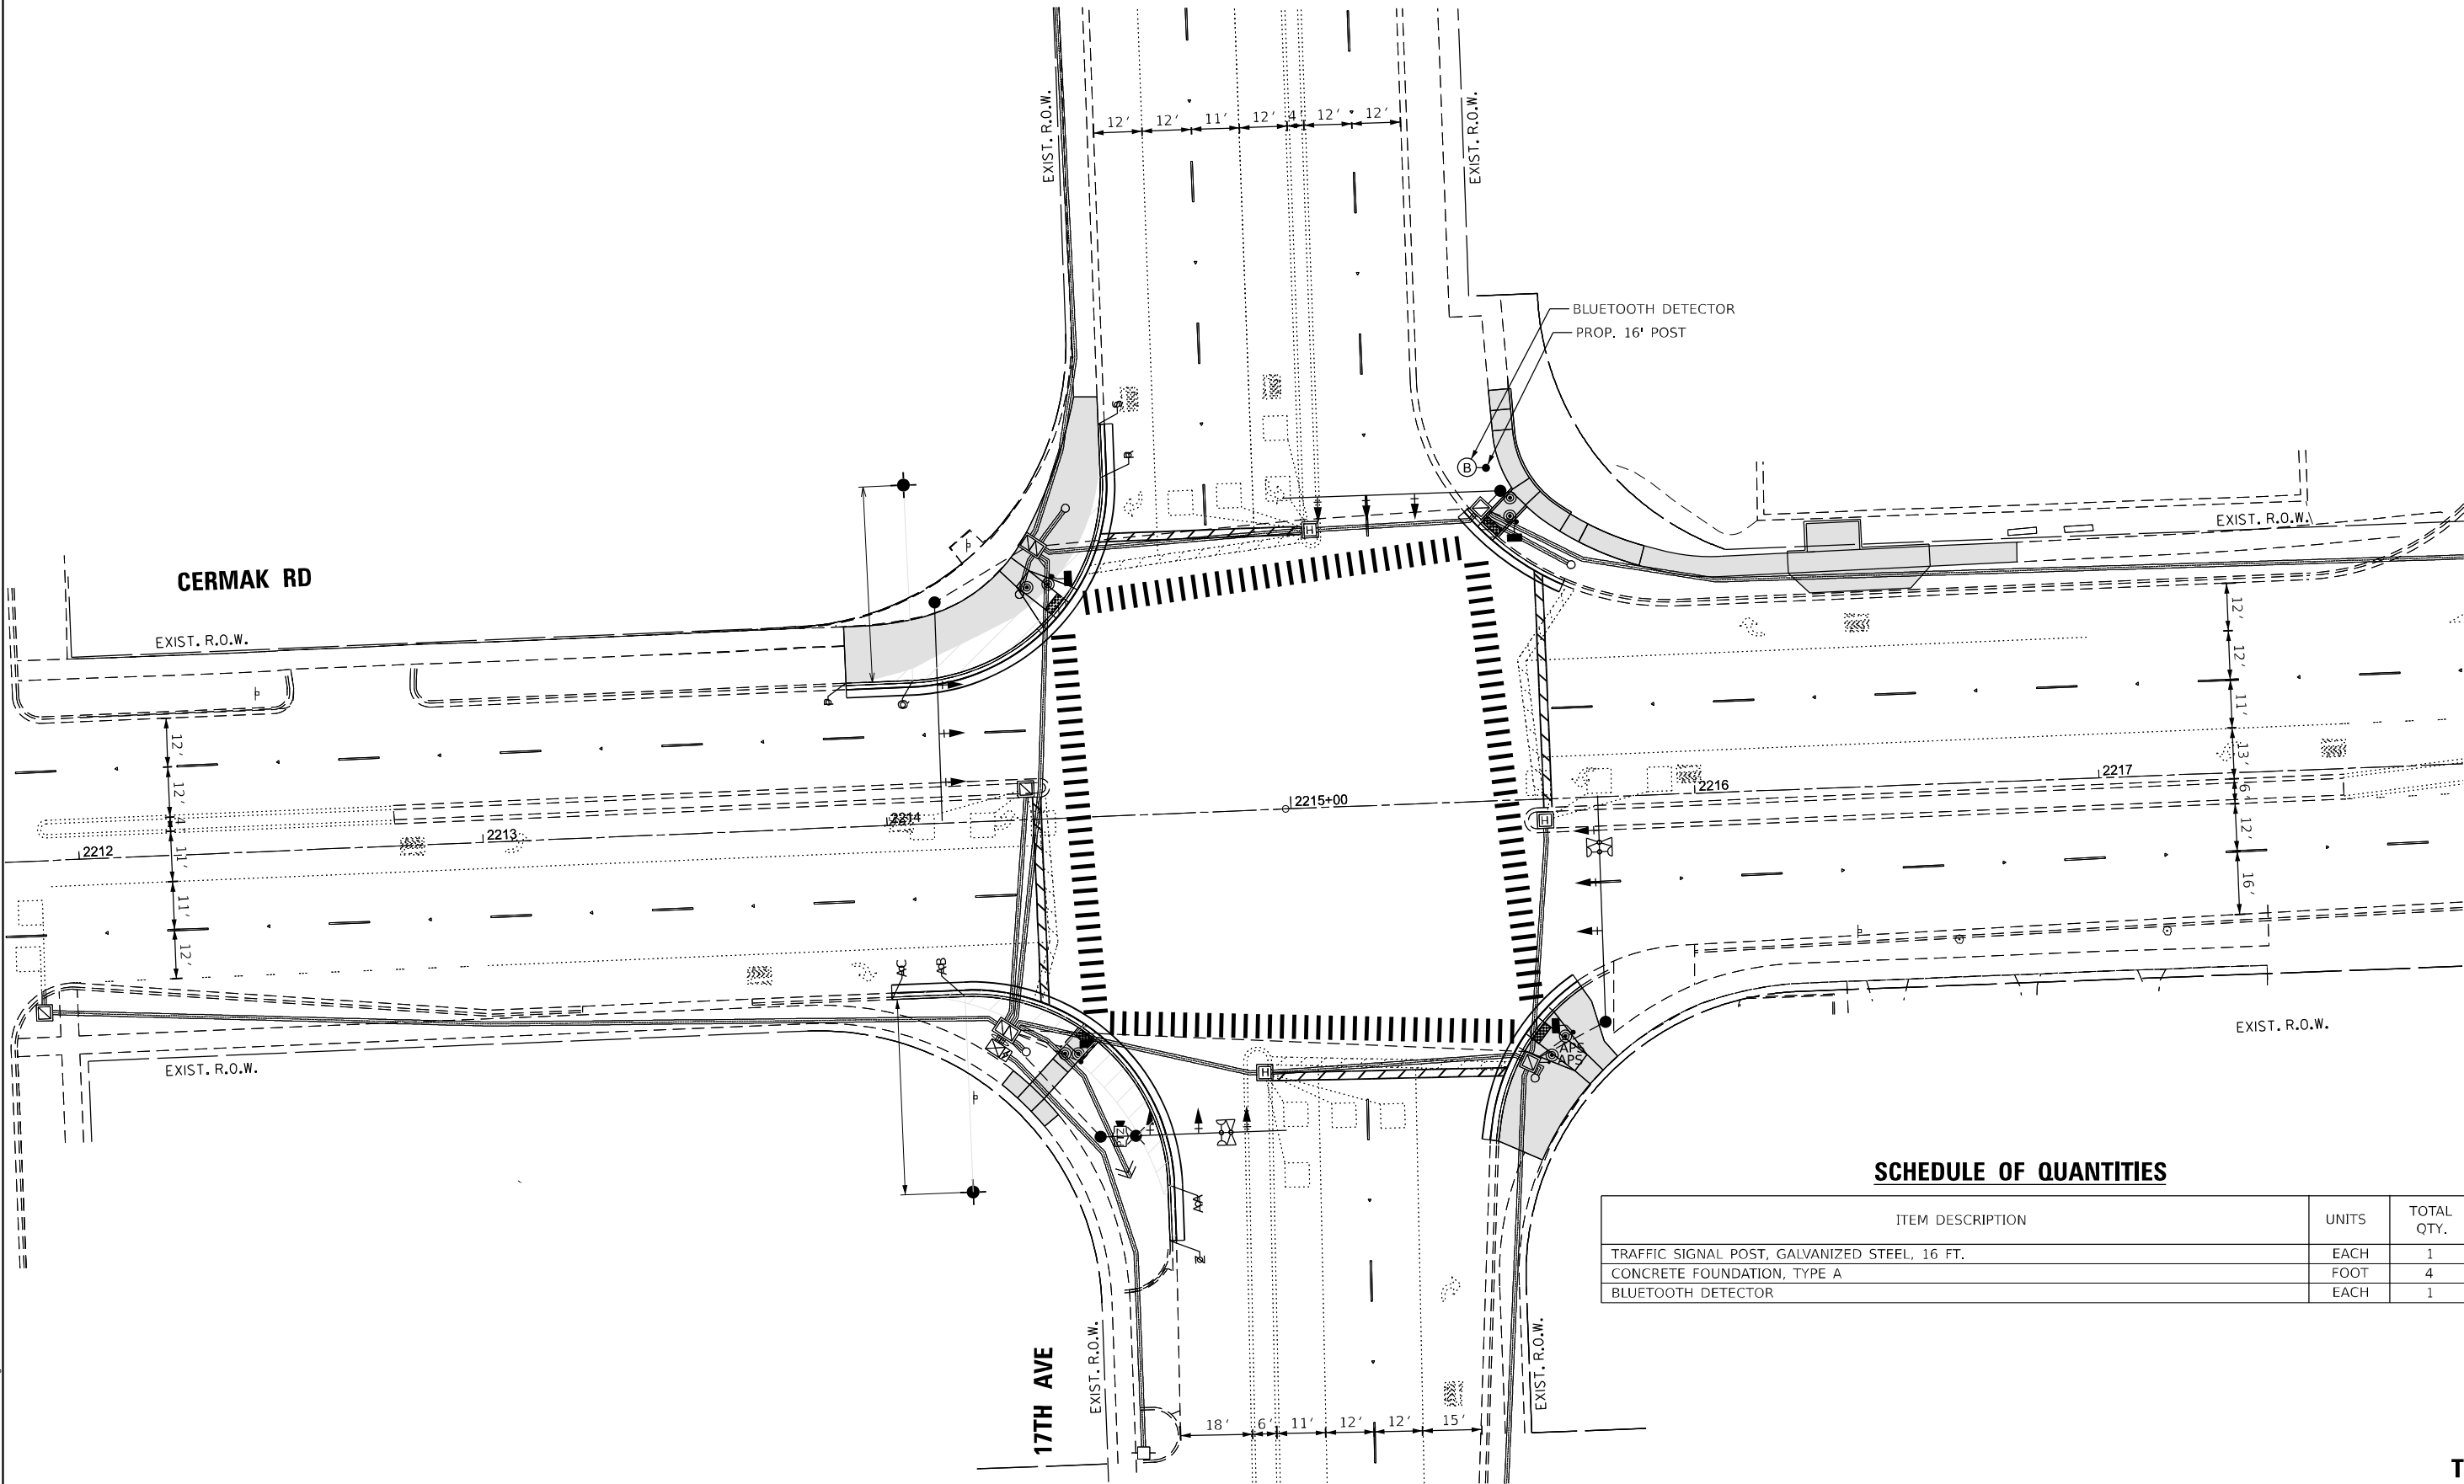



|                        |                   |           |
|------------------------|-------------------|-----------|
| USER NAME = msomer     | DESIGNED - TM     | REVISED - |
|                        | DRAWN - TM, SR    | REVISED - |
| PLOT SCALE = \$SCALE\$ | CHECKED - JAR     | REVISED - |
| PLOT DATE = 03/19/2025 | DATE - 05/23/2024 | REVISED - |


STATE OF ILLINOIS  
DEPARTMENT OF TRANSPORTATION

BLUETOOTH INSTALLATION PLAN  
CERMAK RD AND 12TH AVE

SCALE: 1" = 20' SHEET OF SHEETS STA. TO STA.

| F.A.U. RTE.        | SECTION               | COUNTY           | TOTAL SHEETS | SHEET NO. |
|--------------------|-----------------------|------------------|--------------|-----------|
| 1453               | 2020-266-SUR, SW & TS | COOK/DUPAGE      | 492          | 331       |
| CONTRACT NO. 62N39 |                       |                  |              |           |
| ILLINOIS           |                       | FED. AID PROJECT |              |           |

TS 22065  
IDOT CENTRACS  
FORMER ECON 27

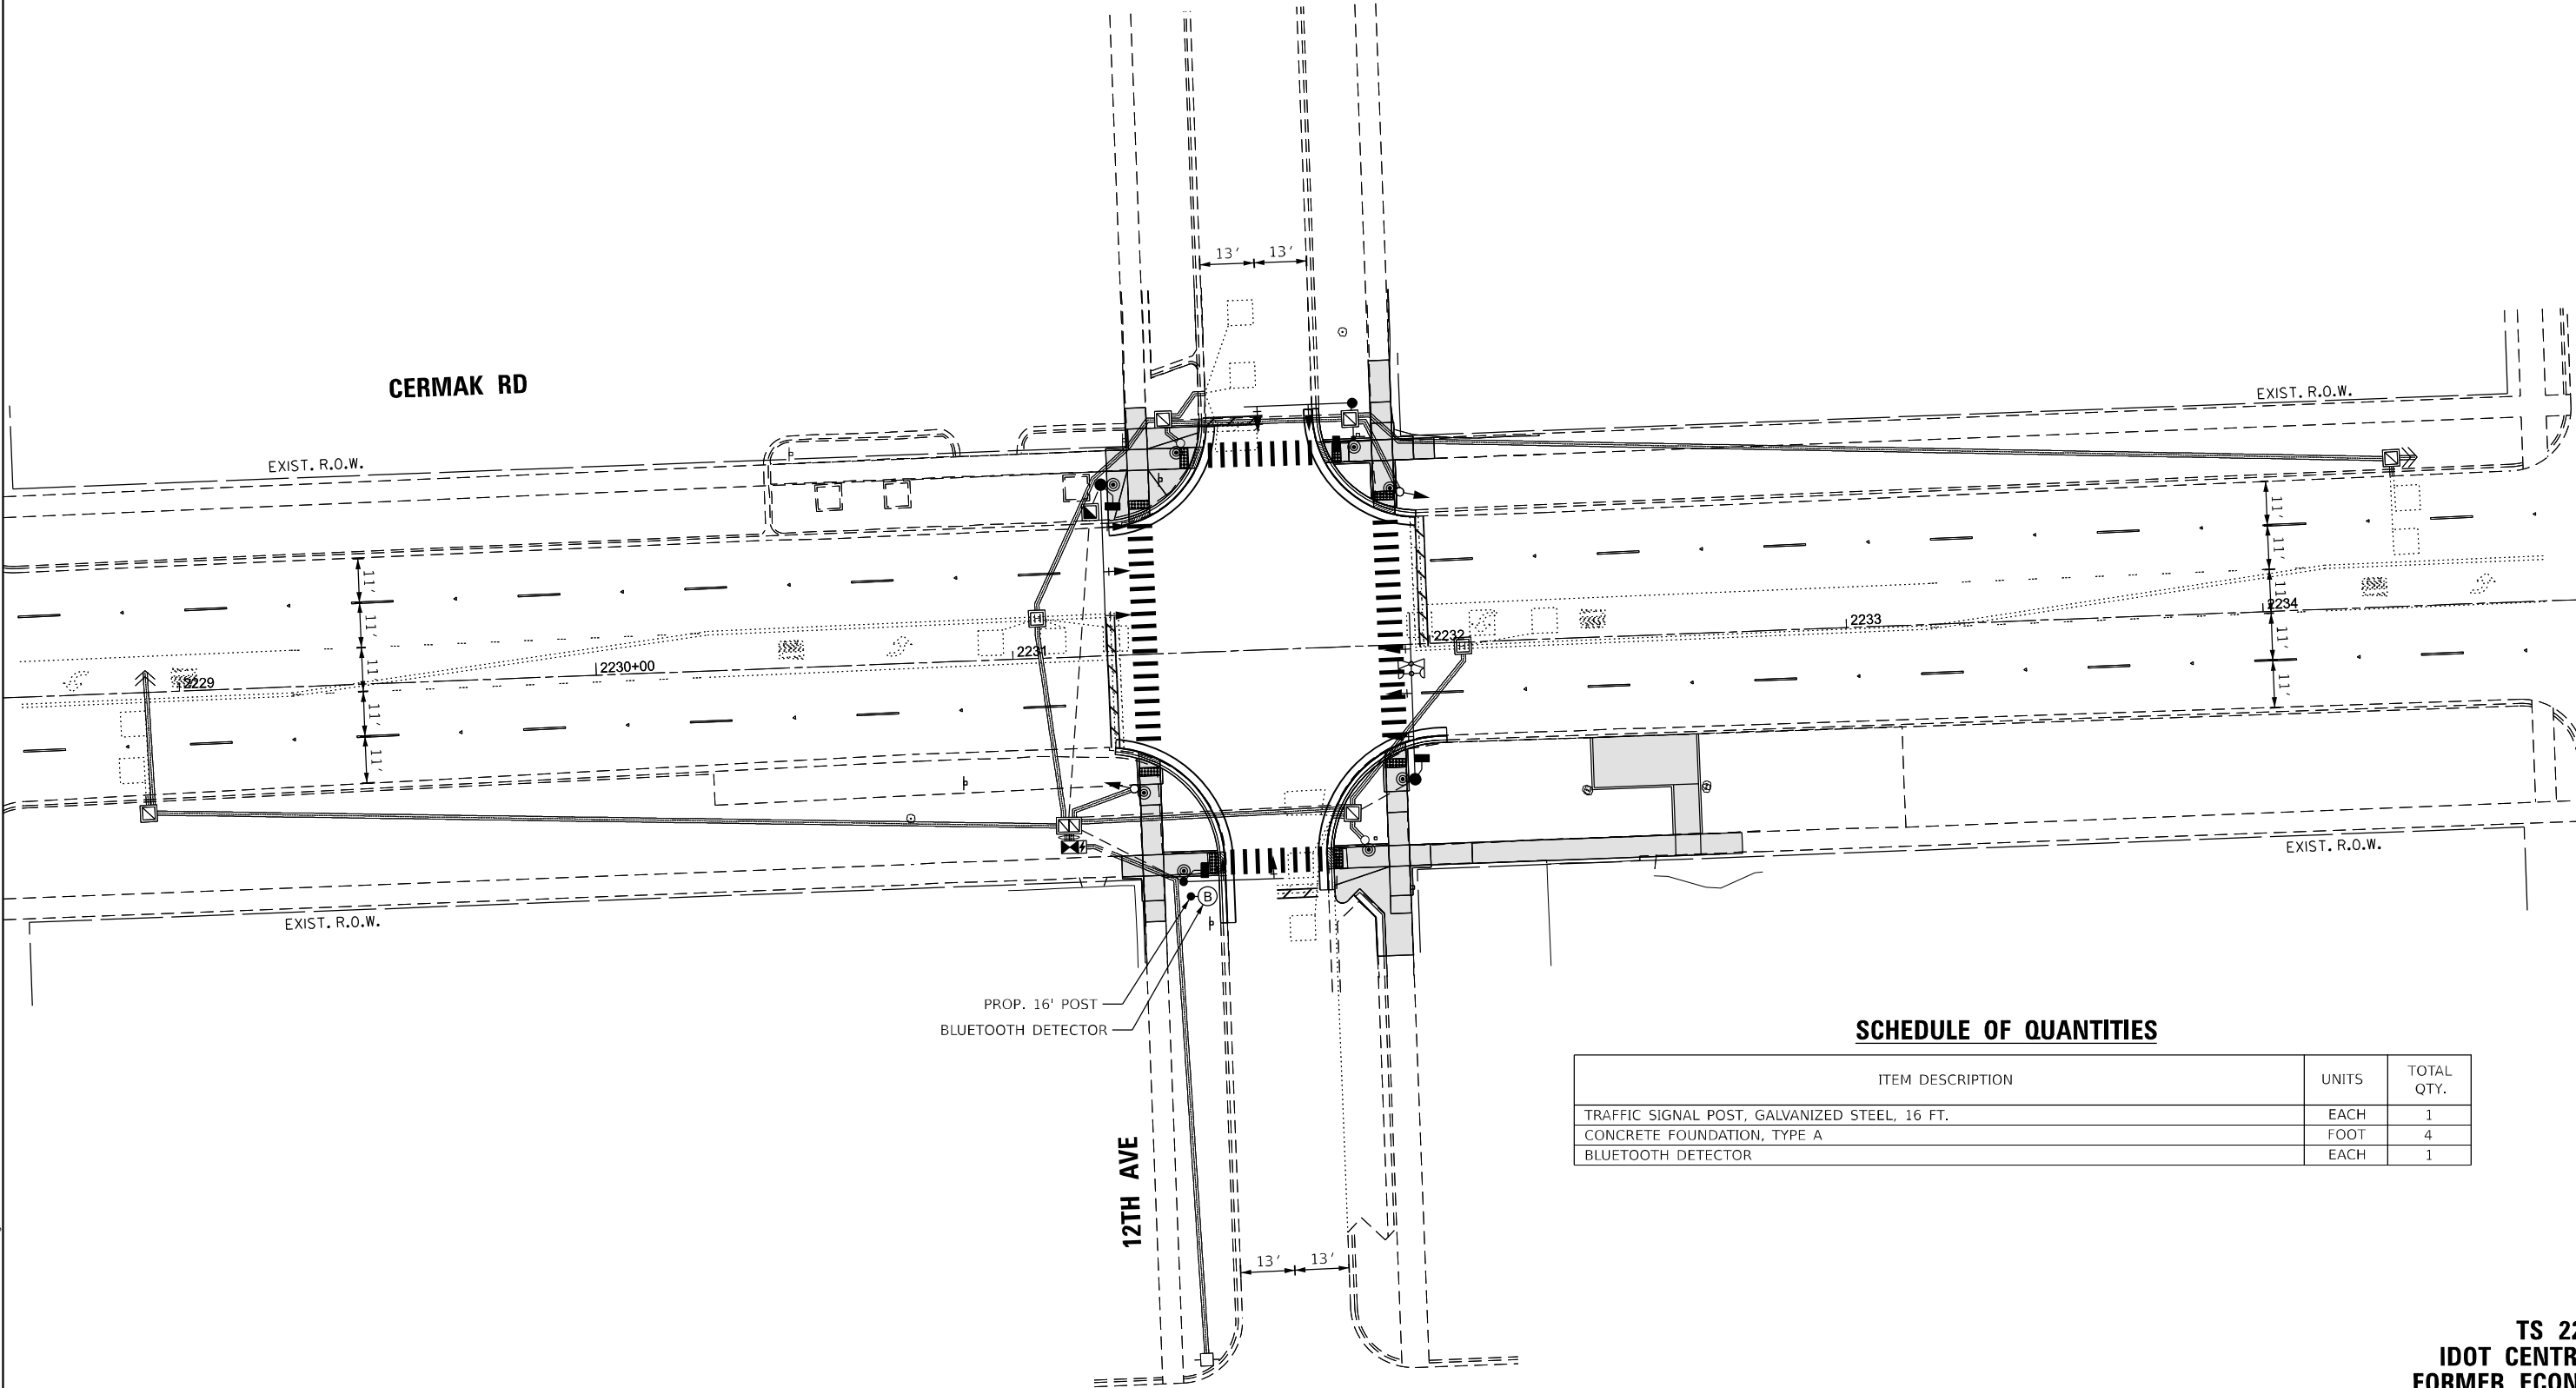

SCHEDULE OF QUANTITIES

| ITEM DESCRIPTION                              | UNITS | TOTAL QTY. |
|-----------------------------------------------|-------|------------|
| TRAFFIC SIGNAL POST, GALVANIZED STEEL, 16 FT. | EACH  | 1          |
| CONCRETE FOUNDATION, TYPE A                   | FOOT  | 4          |
| BLUETOOTH DETECTOR                            | EACH  | 1          |



|            |              |
|------------|--------------|
| USER NAME  | = msomer     |
| PLOT SCALE | = \$SCALE\$  |
| PLOT DATE  | = 03/19/2025 |

|          |              |
|----------|--------------|
| DESIGNED | - TM         |
| DRAWN    | - TM, SR     |
| CHECKED  | - JAR        |
| DATE     | - 05/23/2024 |


|         |   |
|---------|---|
| REVISED | - |
| REVISED | - |
| REVISED | - |
| REVISED | - |

STATE OF ILLINOIS  
DEPARTMENT OF TRANSPORTATION

BLUETOOTH INSTALLATION PLAN  
CERMAK RD AND IL RTE 171 (1ST AVE)

SCALE: 1" = 20' SHEET OF SHEETS STA. TO STA.

| F.A.U. RTE.               | SECTION               | COUNTY      | TOTAL SHEETS | SHEET NO. |
|---------------------------|-----------------------|-------------|--------------|-----------|
| 1453                      | 2020-266-SUR, SW & TS | COOK/DUPAGE | 492          | 332       |
| CONTRACT NO. 62N39        |                       |             |              |           |
| ILLINOIS FED. AID PROJECT |                       |             |              |           |

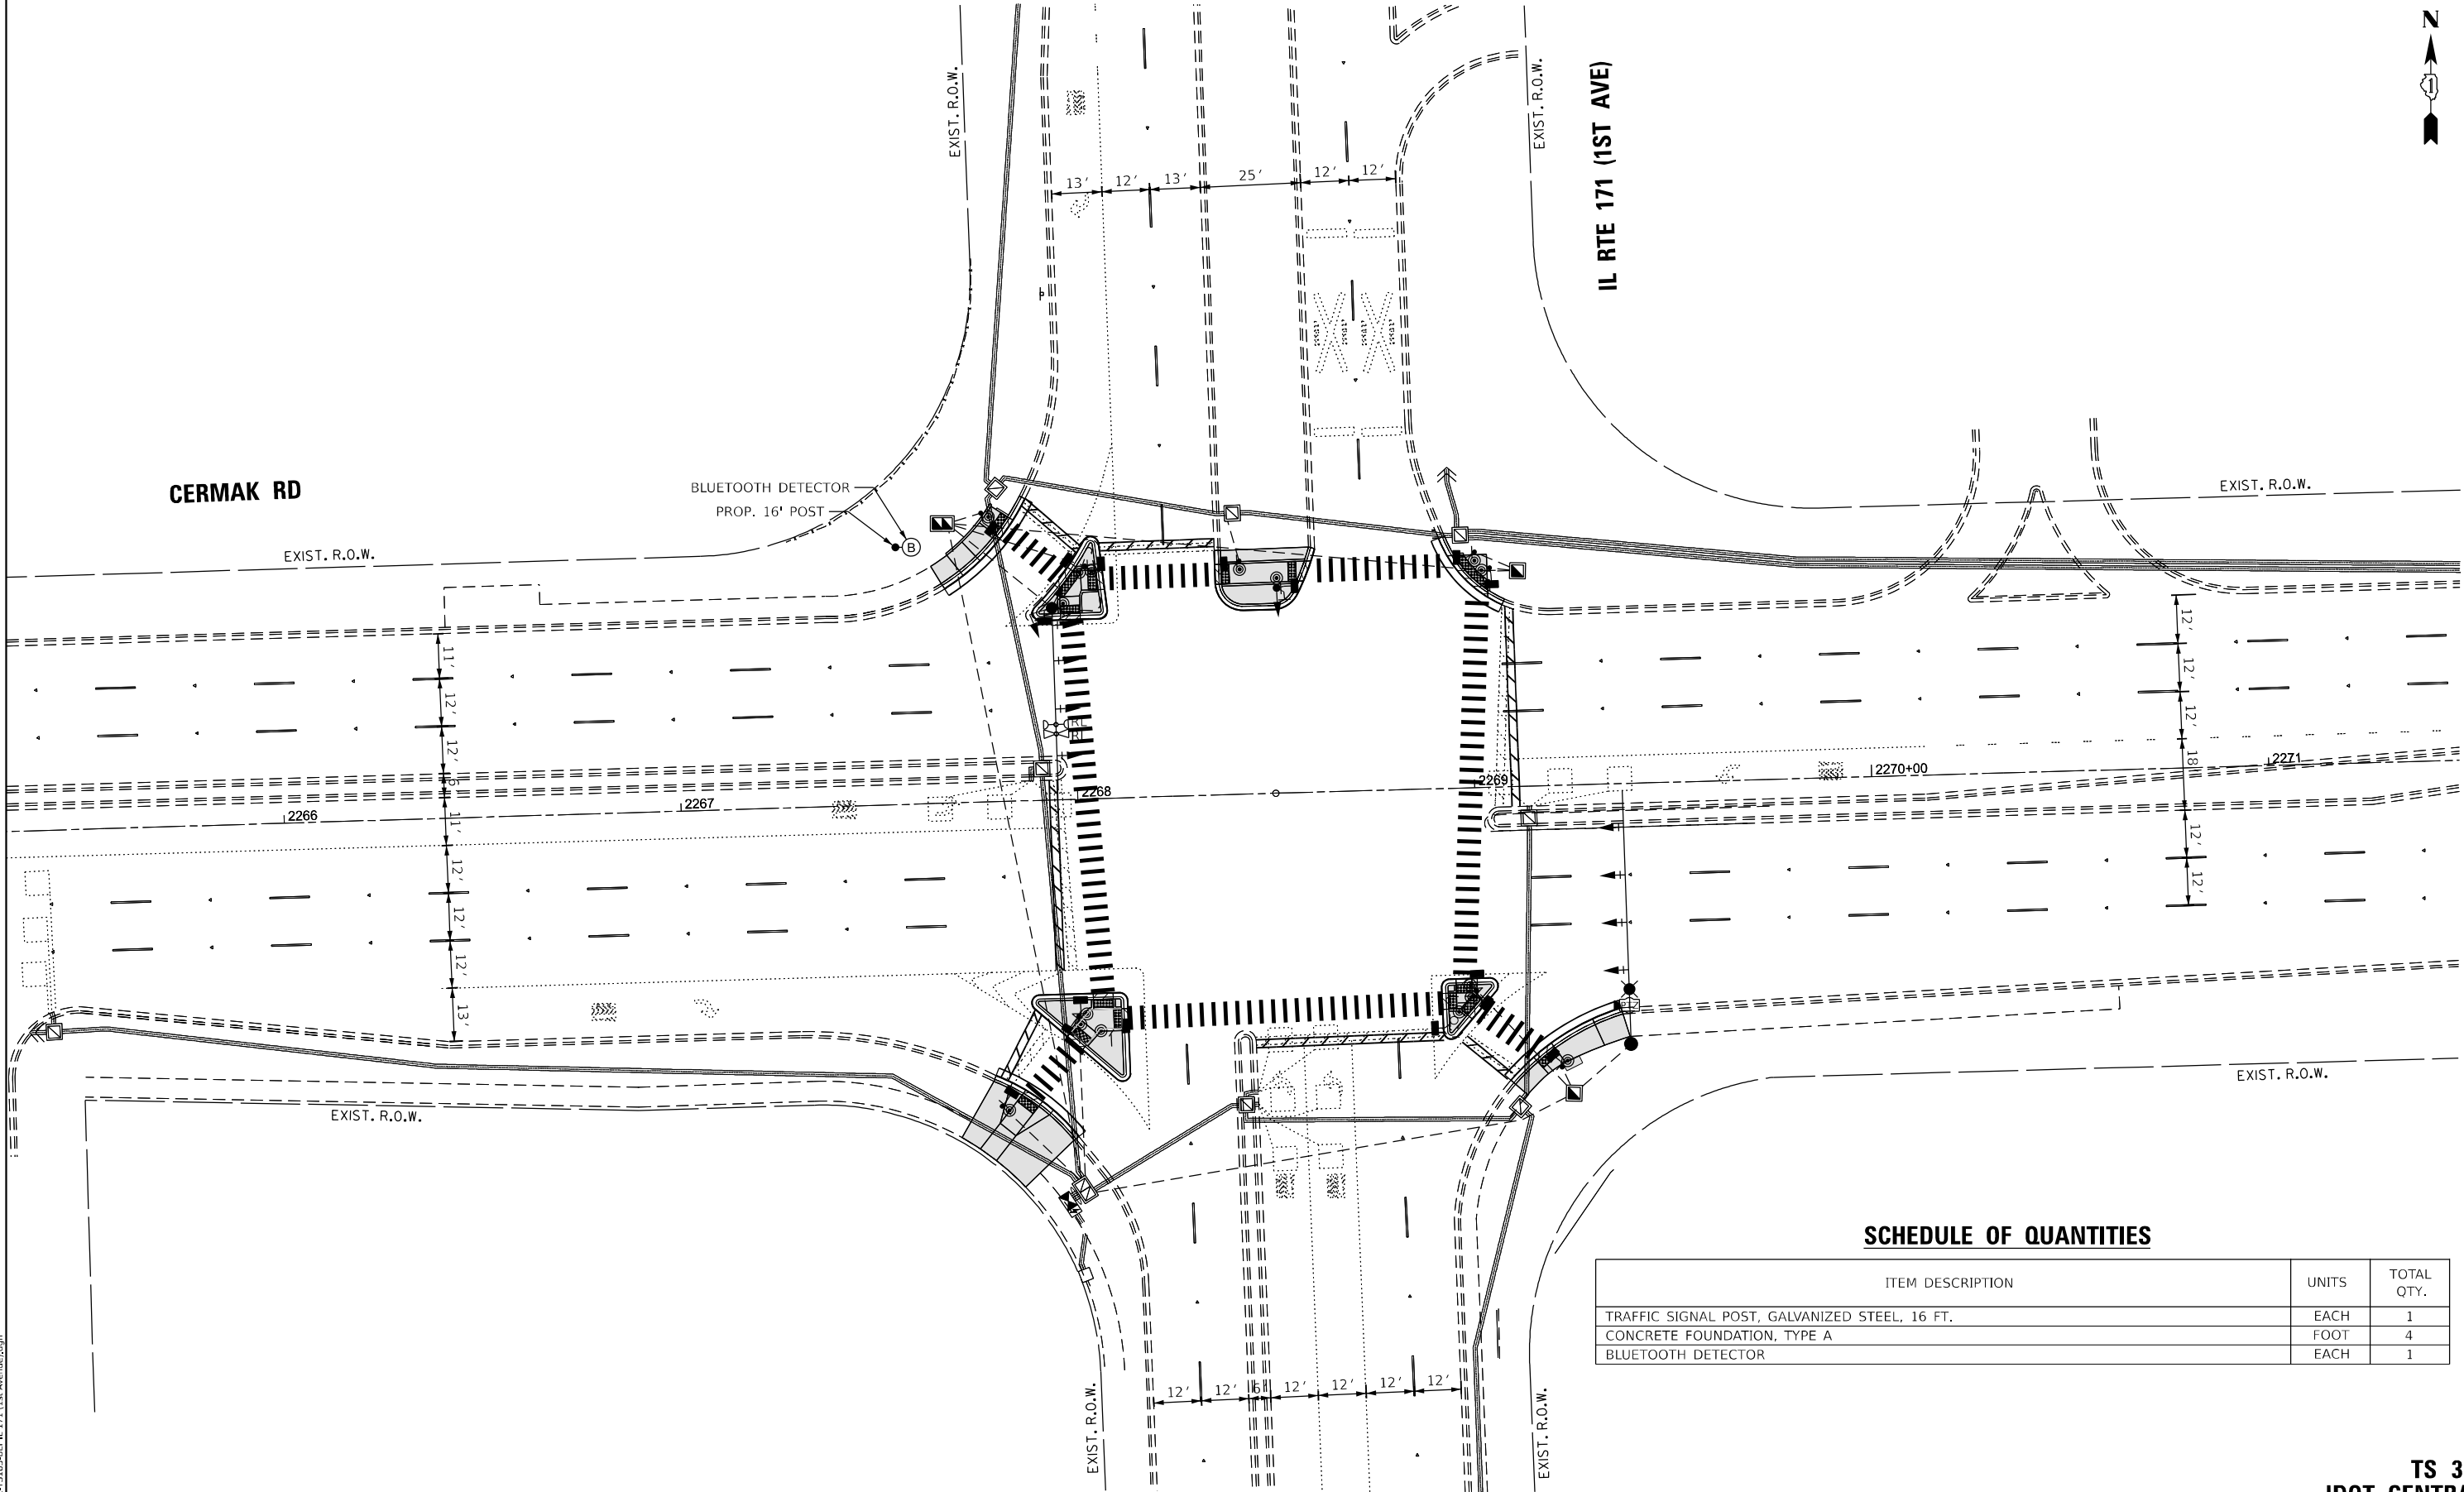

SCHEDULE OF QUANTITIES

| ITEM DESCRIPTION                              | UNITS | TOTAL QTY. |
|-----------------------------------------------|-------|------------|
| TRAFFIC SIGNAL POST, GALVANIZED STEEL, 16 FT. | EACH  | 1          |
| CONCRETE FOUNDATION, TYPE A                   | FOOT  | 4          |
| BLUETOOTH DETECTOR                            | EACH  | 1          |



USER NAME = msomer  
PLOT SCALE = \$SCALE\$  
PLOT DATE = 03/19/2025

DESIGNED - TM  
DRAWN - TM, SR  
CHECKED - JAR  
DATE - 05/23/2024

REVISED -  
REVISED -  
REVISED -  
REVISED -


STATE OF ILLINOIS  
DEPARTMENT OF TRANSPORTATION

BLUETOOTH INSTALLATION PLAN  
CERMAK RD AND DES PLAINES AVE

SCALE: 1" = 20' SHEET OF SHEETS STA. TO STA.

| F.A.U. RTE.               | SECTION               | COUNTY      | TOTAL SHEETS | SHEET NO. |
|---------------------------|-----------------------|-------------|--------------|-----------|
| 1453                      | 2020-266-SUR, SW & TS | COOK/DUPAGE | 492          | 333       |
| CONTRACT NO. 62N39        |                       |             |              |           |
| ILLINOIS FED. AID PROJECT |                       |             |              |           |

TS 4800  
IDOT CENTRACS  
FORMER ECON 27

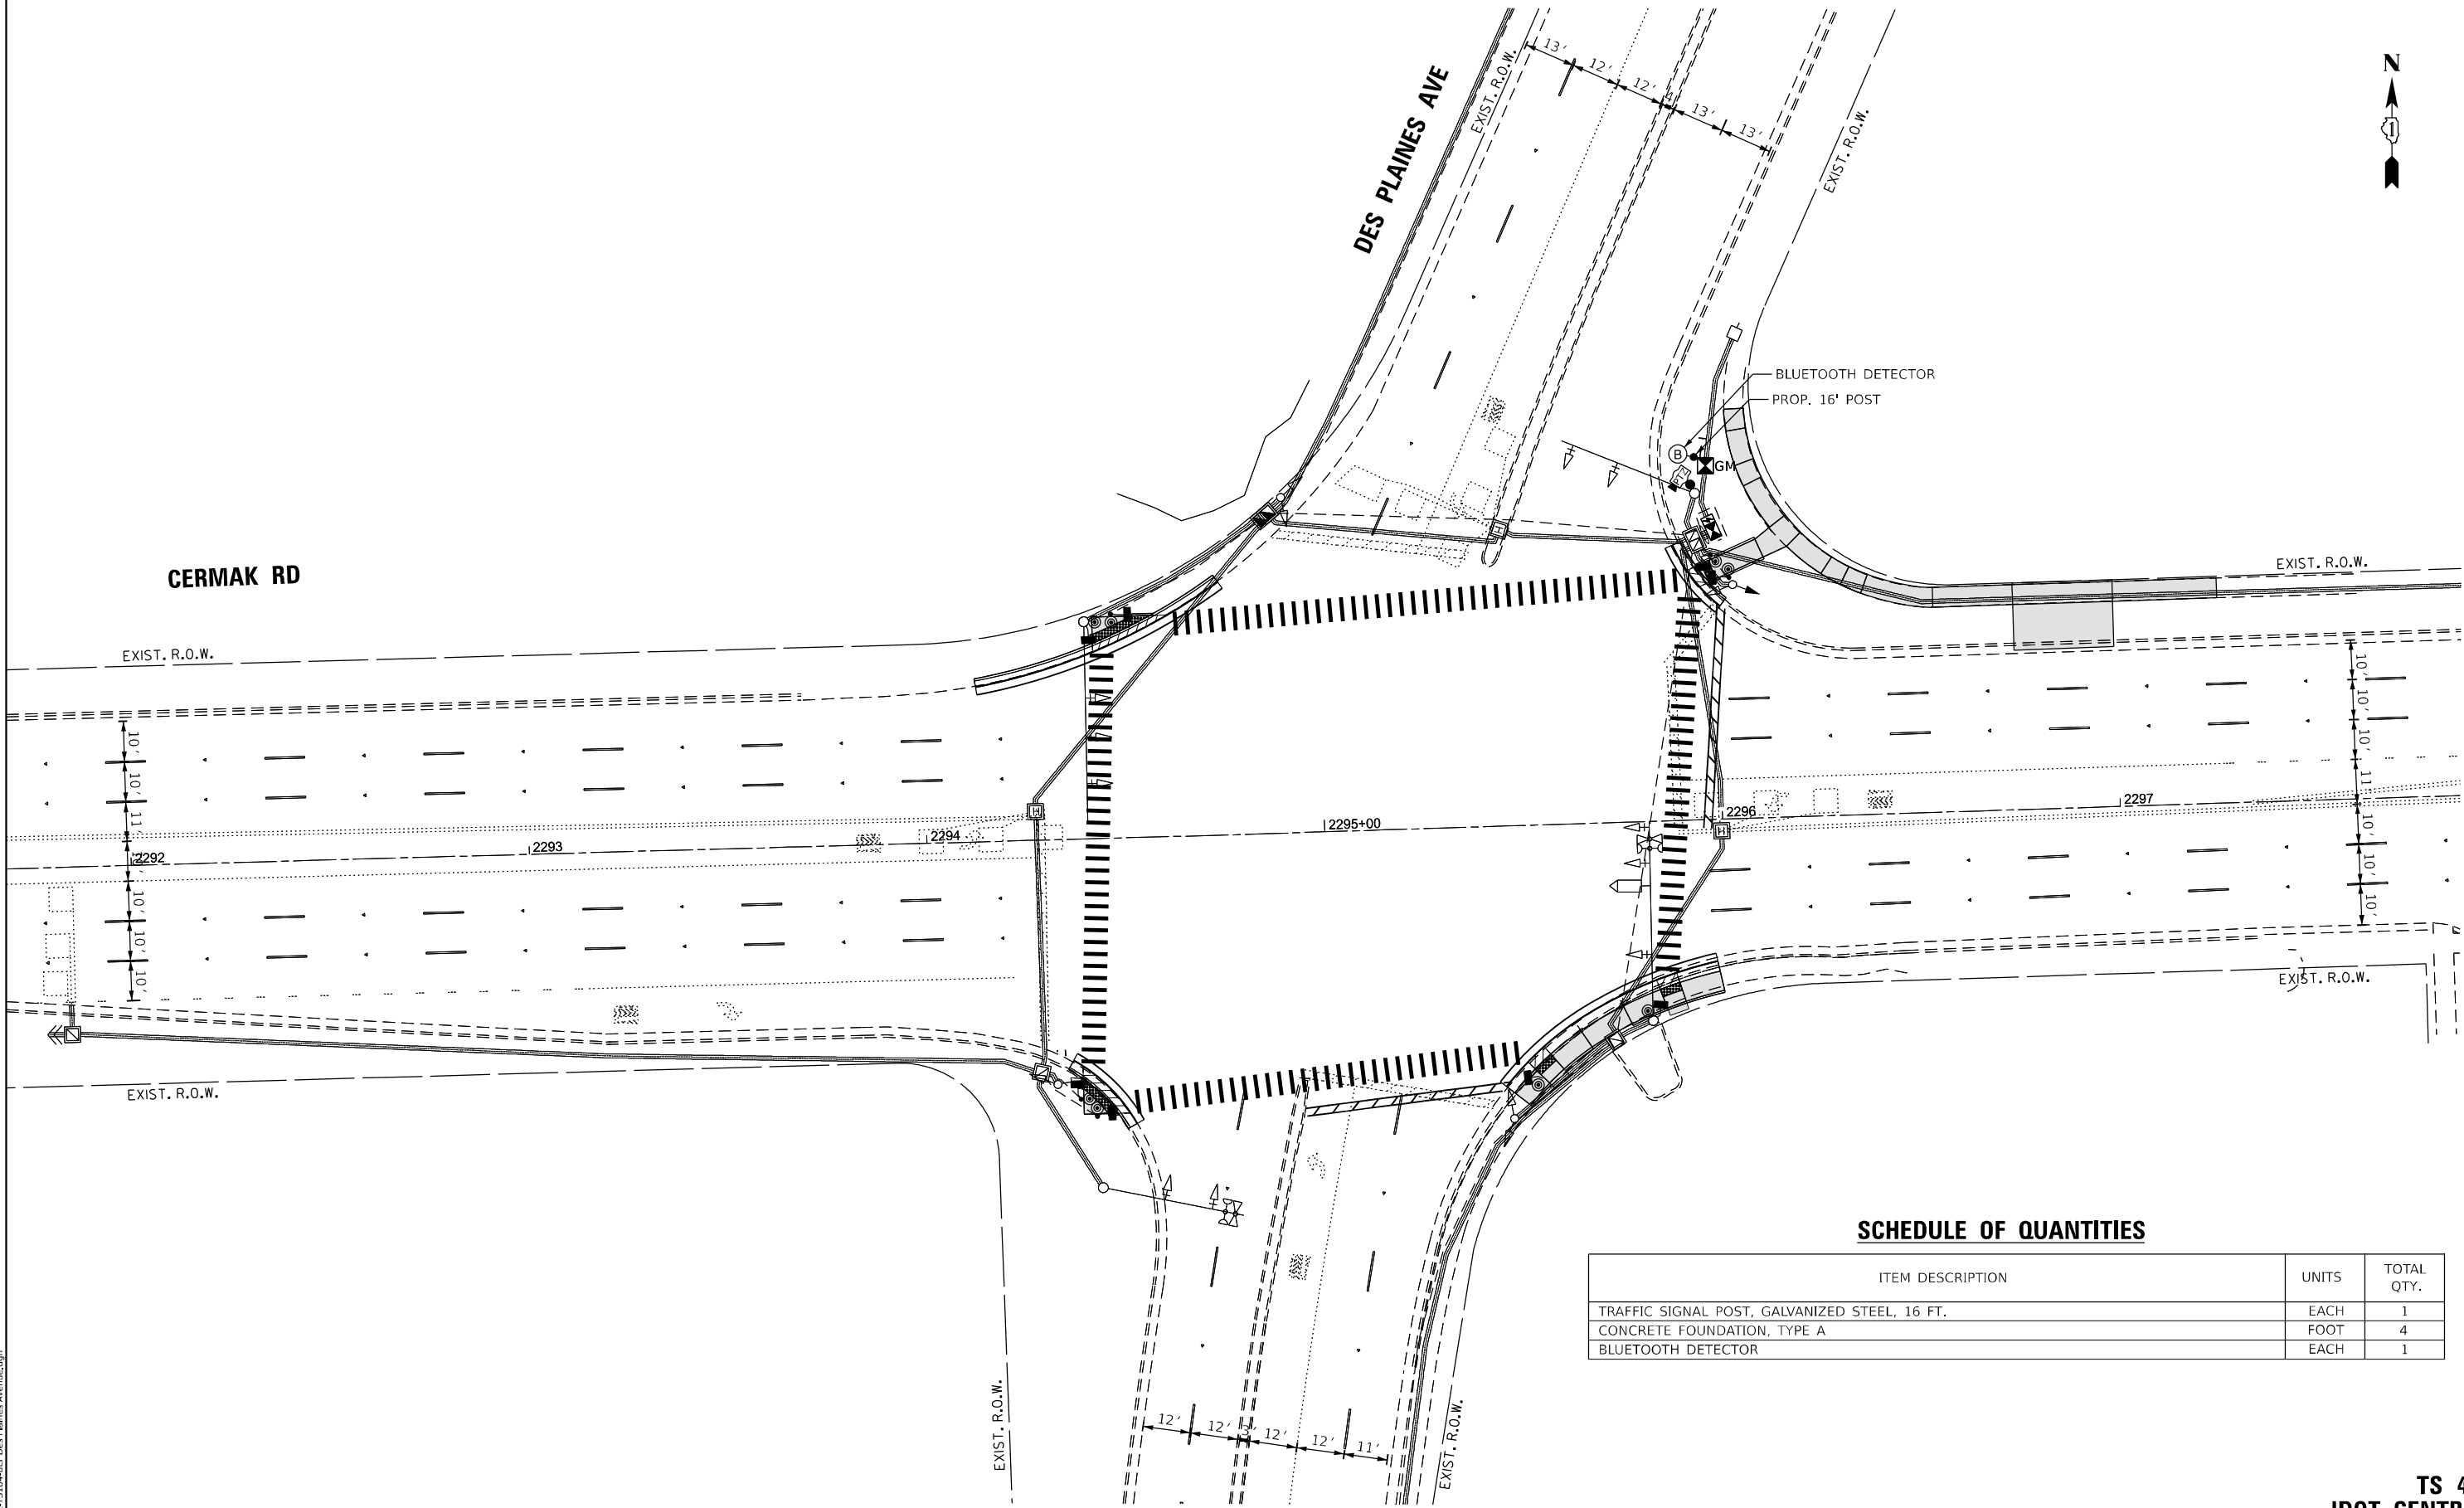


SCHEDULE OF QUANTITIES

| ITEM DESCRIPTION                              | UNITS | TOTAL QTY. |
|-----------------------------------------------|-------|------------|
| TRAFFIC SIGNAL POST, GALVANIZED STEEL, 16 FT. | EACH  | 1          |
| CONCRETE FOUNDATION, TYPE A                   | FOOT  | 4          |
| BLUETOOTH DETECTOR                            | EACH  | 1          |

|            |              |            |            |           |  |
|------------|--------------|------------|------------|-----------|--|
| USER NAME  | = msomer     | DESIGNED - | TM         | REVISED - |  |
|            |              | DRAWN -    | TM, SR     | REVISED - |  |
| PLOT SCALE | = \$SCALE\$  | CHECKED -  | JAR        | REVISED - |  |
| PLOT DATE  | = 03/19/2025 | DATE -     | 05/23/2024 | REVISED - |  |

| F.A.U. RTE.               | SECTION               | COUNTY      | TOTAL SHEETS | SHEET NO. |
|---------------------------|-----------------------|-------------|--------------|-----------|
| 1453                      | 2020-266-SUR, SW & TS | COOK/DUPAGE | 492          | 334       |
| CONTRACT NO. 62N39        |                       |             |              |           |
| ILLINOIS FED. AID PROJECT |                       |             |              |           |

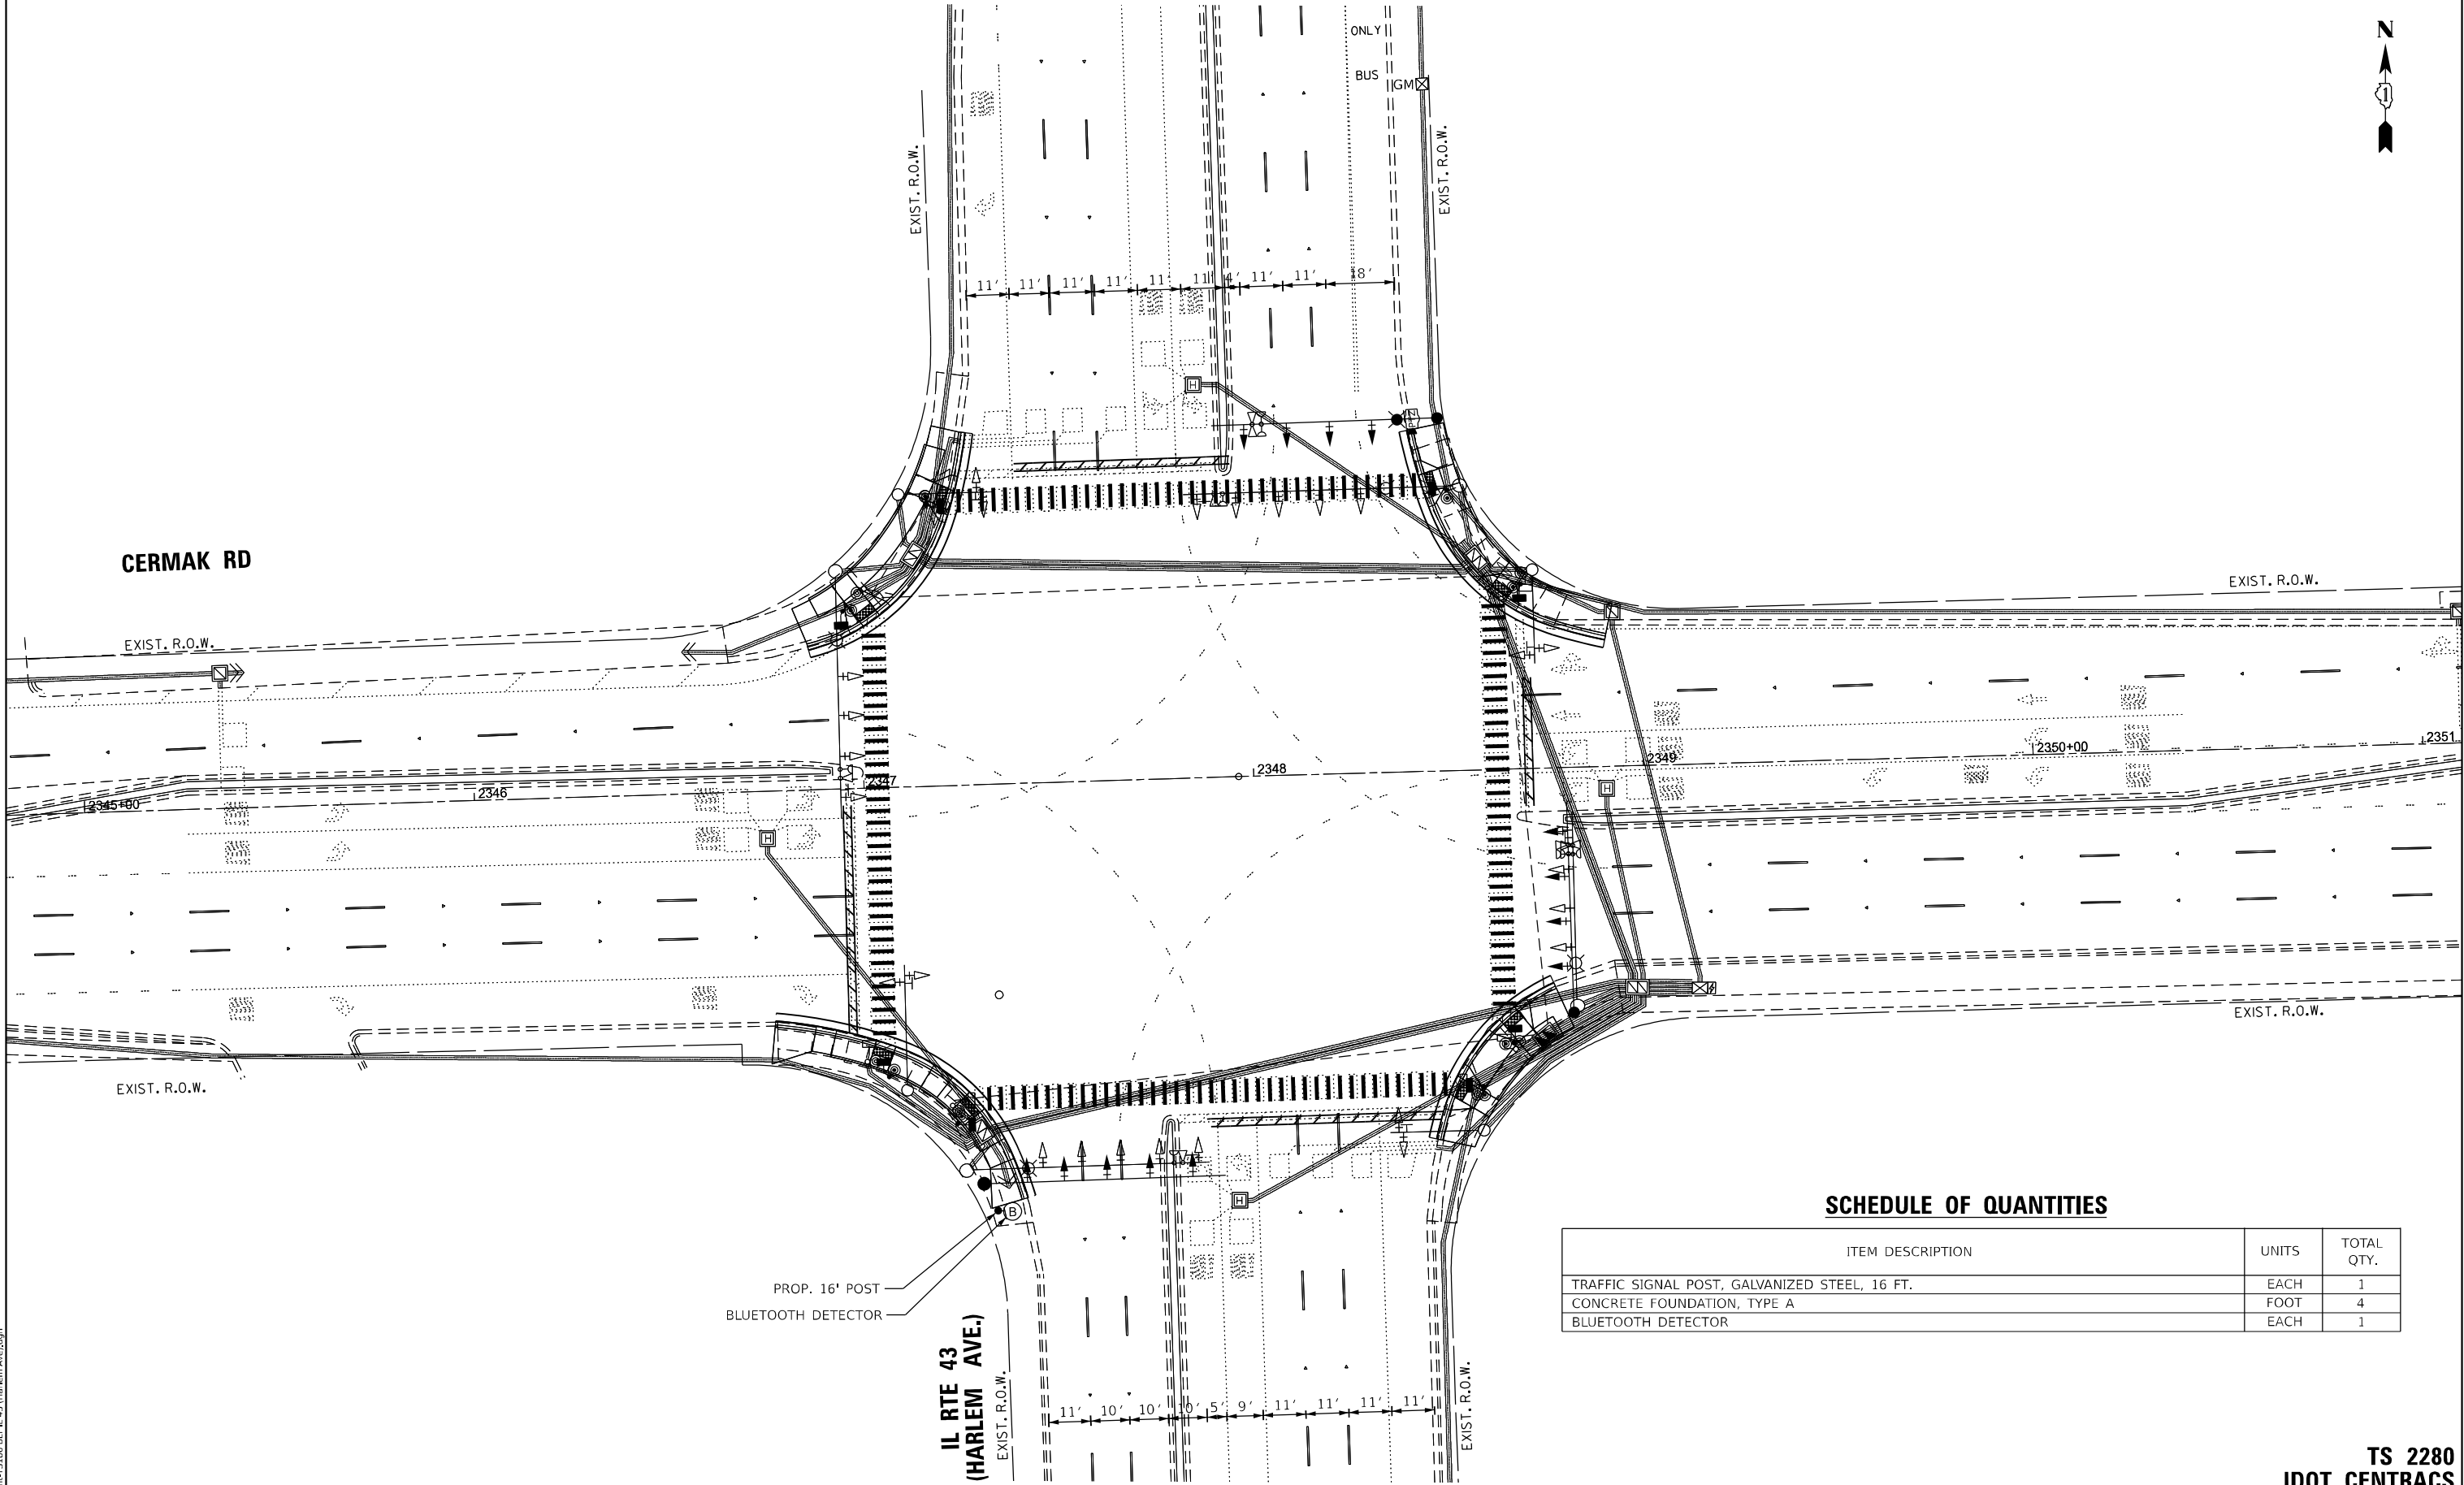

SCHEDULE OF QUANTITIES

| ITEM DESCRIPTION                              | UNITS | TOTAL QTY. |
|-----------------------------------------------|-------|------------|
| TRAFFIC SIGNAL POST, GALVANIZED STEEL, 16 FT. | EACH  | 1          |
| CONCRETE FOUNDATION, TYPE A                   | FOOT  | 4          |
| BLUETOOTH DETECTOR                            | EACH  | 1          |





|                        |                   |           |
|------------------------|-------------------|-----------|
| USER NAME = msomer     | DESIGNED - TM     | REVISED - |
| DRAWN - TM, SR         | REVISED -         |           |
| PLOT SCALE = \$SCALE\$ | CHECKED - JAR     | REVISED - |
| PLOT DATE = 03/19/2025 | DATE - 05/23/2024 | REVISED - |


STATE OF ILLINOIS  
DEPARTMENT OF TRANSPORTATION

BLUETOOTH INSTALLATION PLAN  
CERMAK RD AND OAK PARK AVE

SCALE: 1" = 20' SHEET OF SHEETS STA. TO STA.

| F.A.U. RTE.        | SECTION               | COUNTY           | TOTAL SHEETS | SHEET NO. |
|--------------------|-----------------------|------------------|--------------|-----------|
| 1453               | 2020-266-SUR, SW & TS | COOK/DUPAGE      | 492          | 335       |
| CONTRACT NO. 62N39 |                       |                  |              |           |
| ILLINOIS           |                       | FED. AID PROJECT |              |           |

TS 4830  
IDOT CENTRACS  
FORMER ECON 30

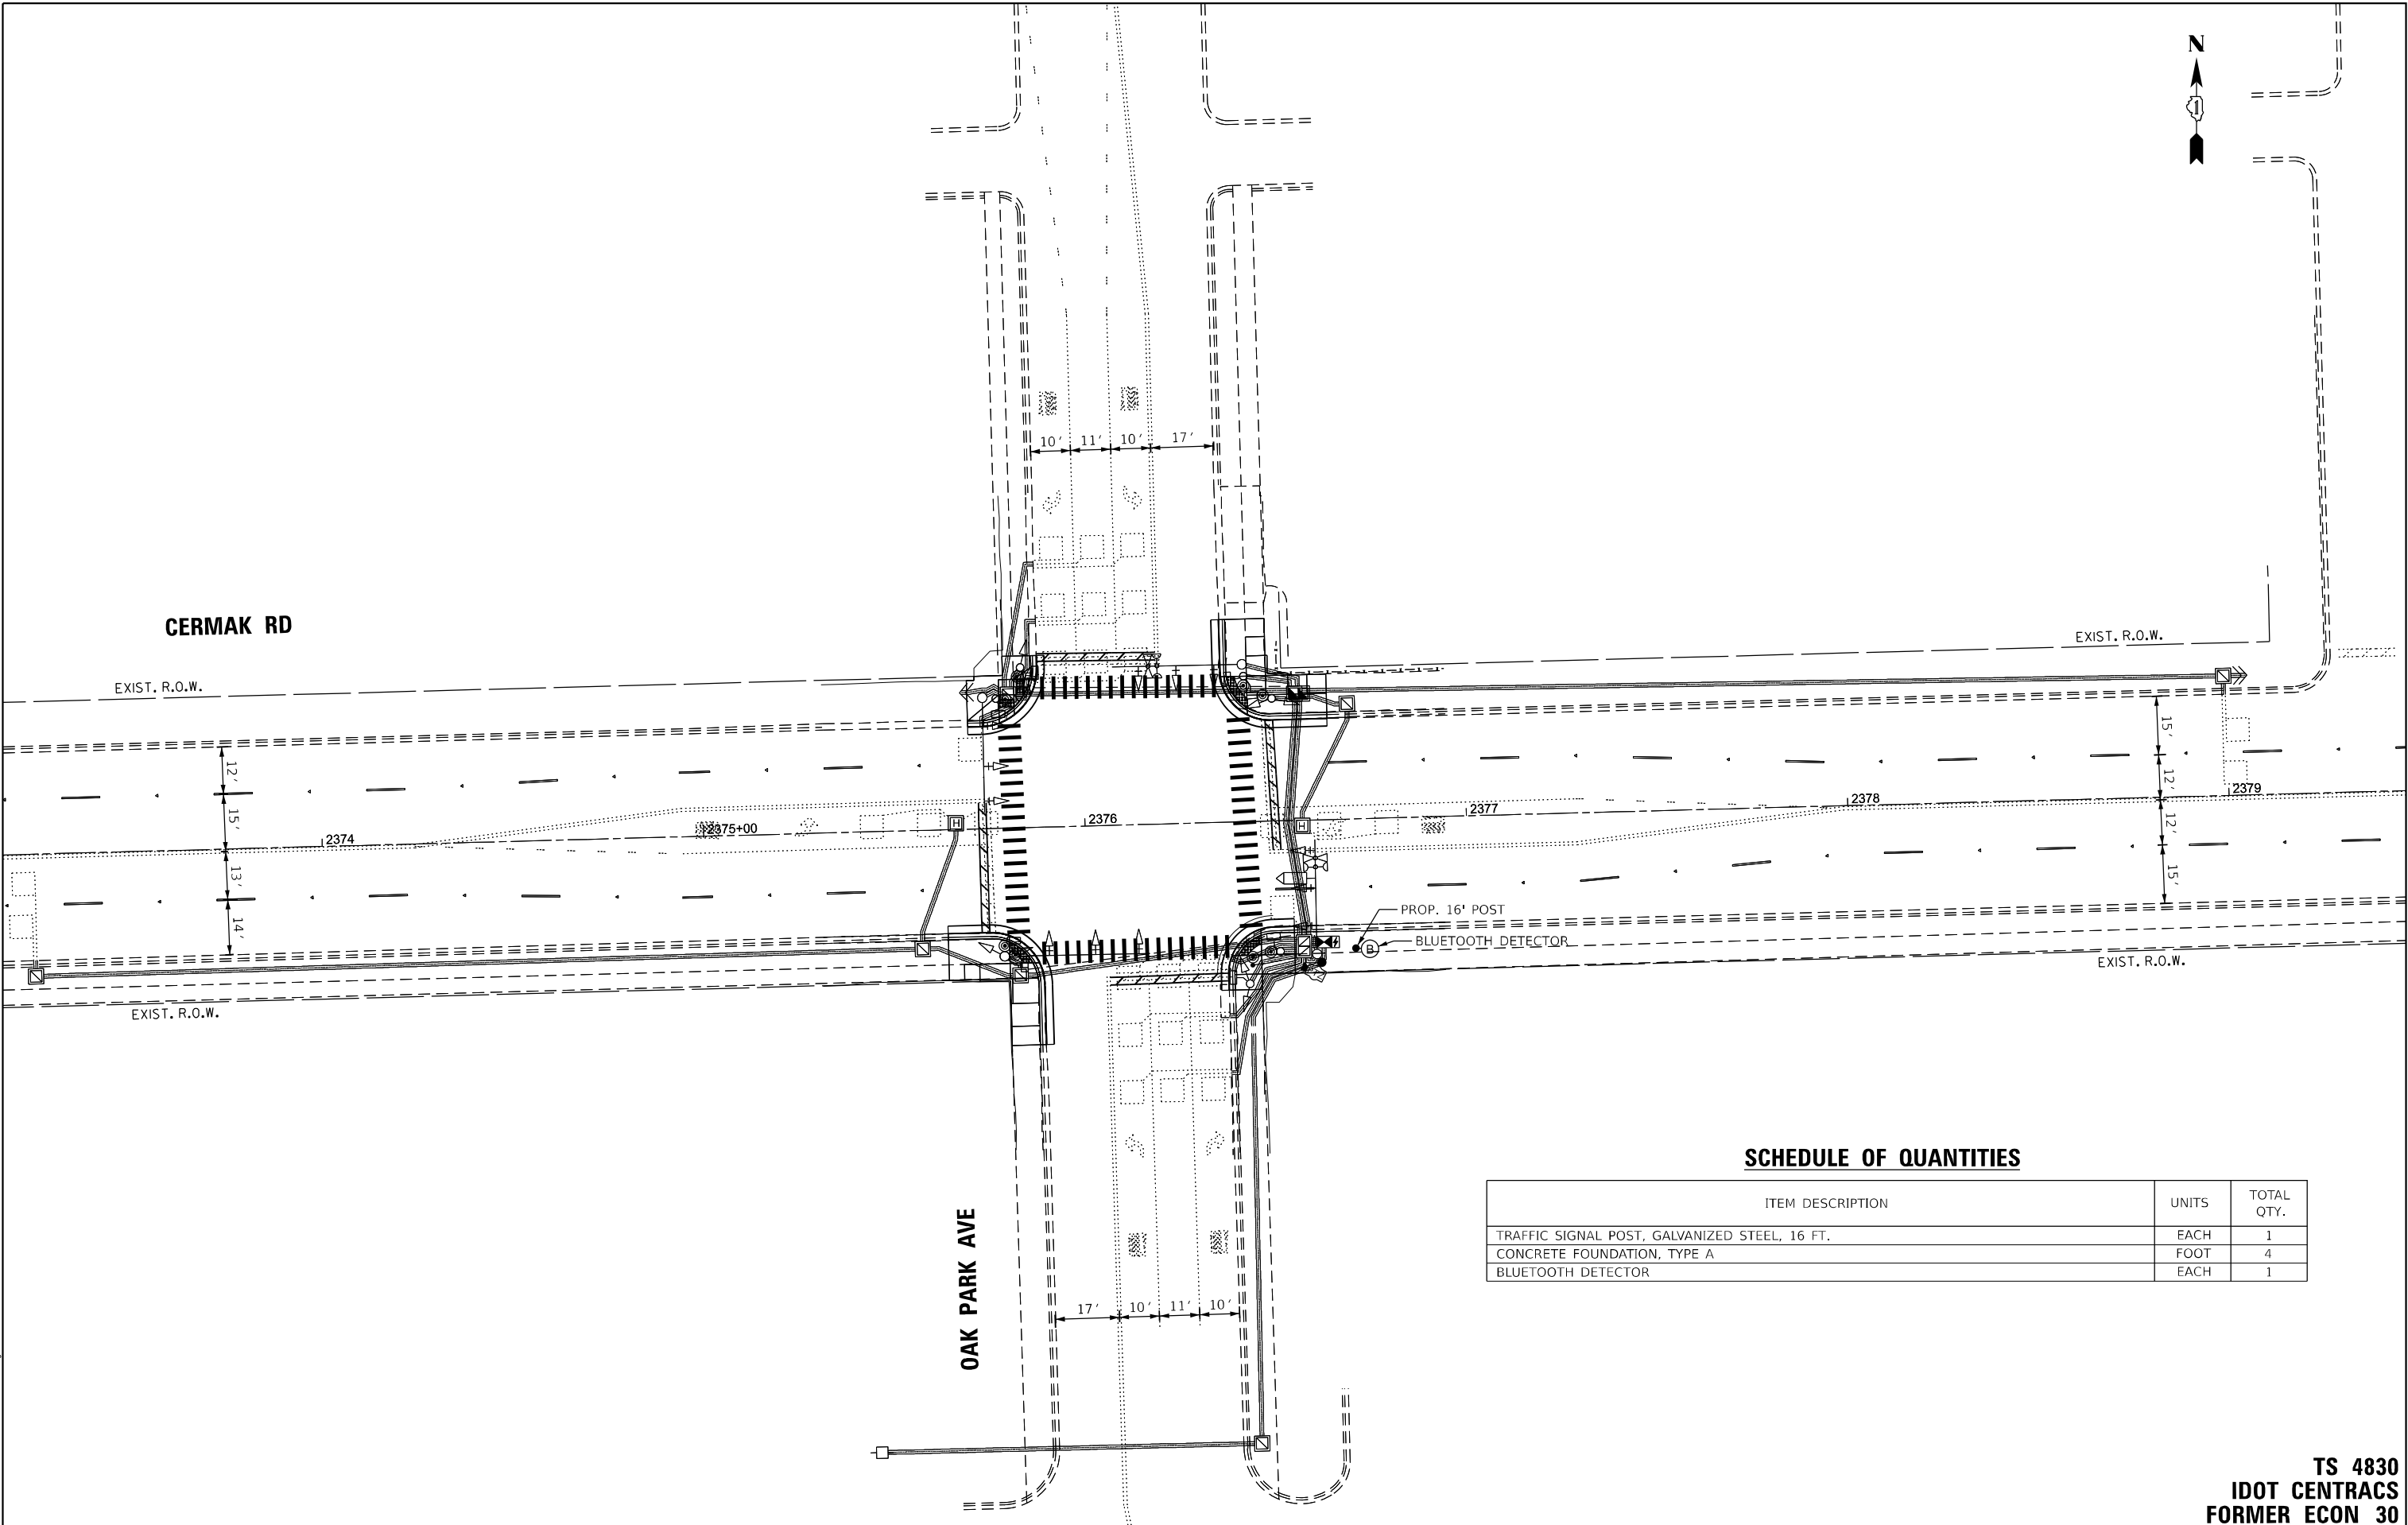

SCHEDULE OF QUANTITIES

| ITEM DESCRIPTION                              | UNITS | TOTAL QTY. |
|-----------------------------------------------|-------|------------|
| TRAFFIC SIGNAL POST, GALVANIZED STEEL, 16 FT. | EACH  | 1          |
| CONCRETE FOUNDATION, TYPE A                   | FOOT  | 4          |
| BLUETOOTH DETECTOR                            | EACH  | 1          |



|                        |                   |           |
|------------------------|-------------------|-----------|
| USER NAME = msomer     | DESIGNED - TM     | REVISED - |
|                        | DRAWN - TM, SR    | REVISED - |
| PLOT SCALE = \$SCALE\$ | CHECKED - JAR     | REVISED - |
| PLOT DATE = 03/19/2025 | DATE - 05/23/2024 | REVISED - |

STATE OF ILLINOIS  
DEPARTMENT OF TRANSPORTATION

BLUETOOTH INSTALLATION PLAN  
CERMAK RD AND RIDGELAND AVE


SCALE: 1" = 20' SHEET OF SHEETS STA. TO STA.

| F.A.U. RTE.        | SECTION               | COUNTY           | TOTAL SHEETS | SHEET NO. |
|--------------------|-----------------------|------------------|--------------|-----------|
| 1453               | 2020-266-SUR, SW & TS | COOK/DUPAGE      | 492          | 336       |
| CONTRACT NO. 62N39 |                       |                  |              |           |
| ILLINOIS           |                       | FED. AID PROJECT |              |           |

TS 4835  
IDOT CENTRACS  
FORMER ECON 30

SCHEDULE OF QUANTITIES

| ITEM DESCRIPTION                              | UNITS | TOTAL QTY. |
|-----------------------------------------------|-------|------------|
| TRAFFIC SIGNAL POST, GALVANIZED STEEL, 16 FT. | EACH  | 1          |
| CONCRETE FOUNDATION, TYPE A                   | FOOT  | 4          |
| BLUETOOTH DETECTOR                            | EACH  | 1          |

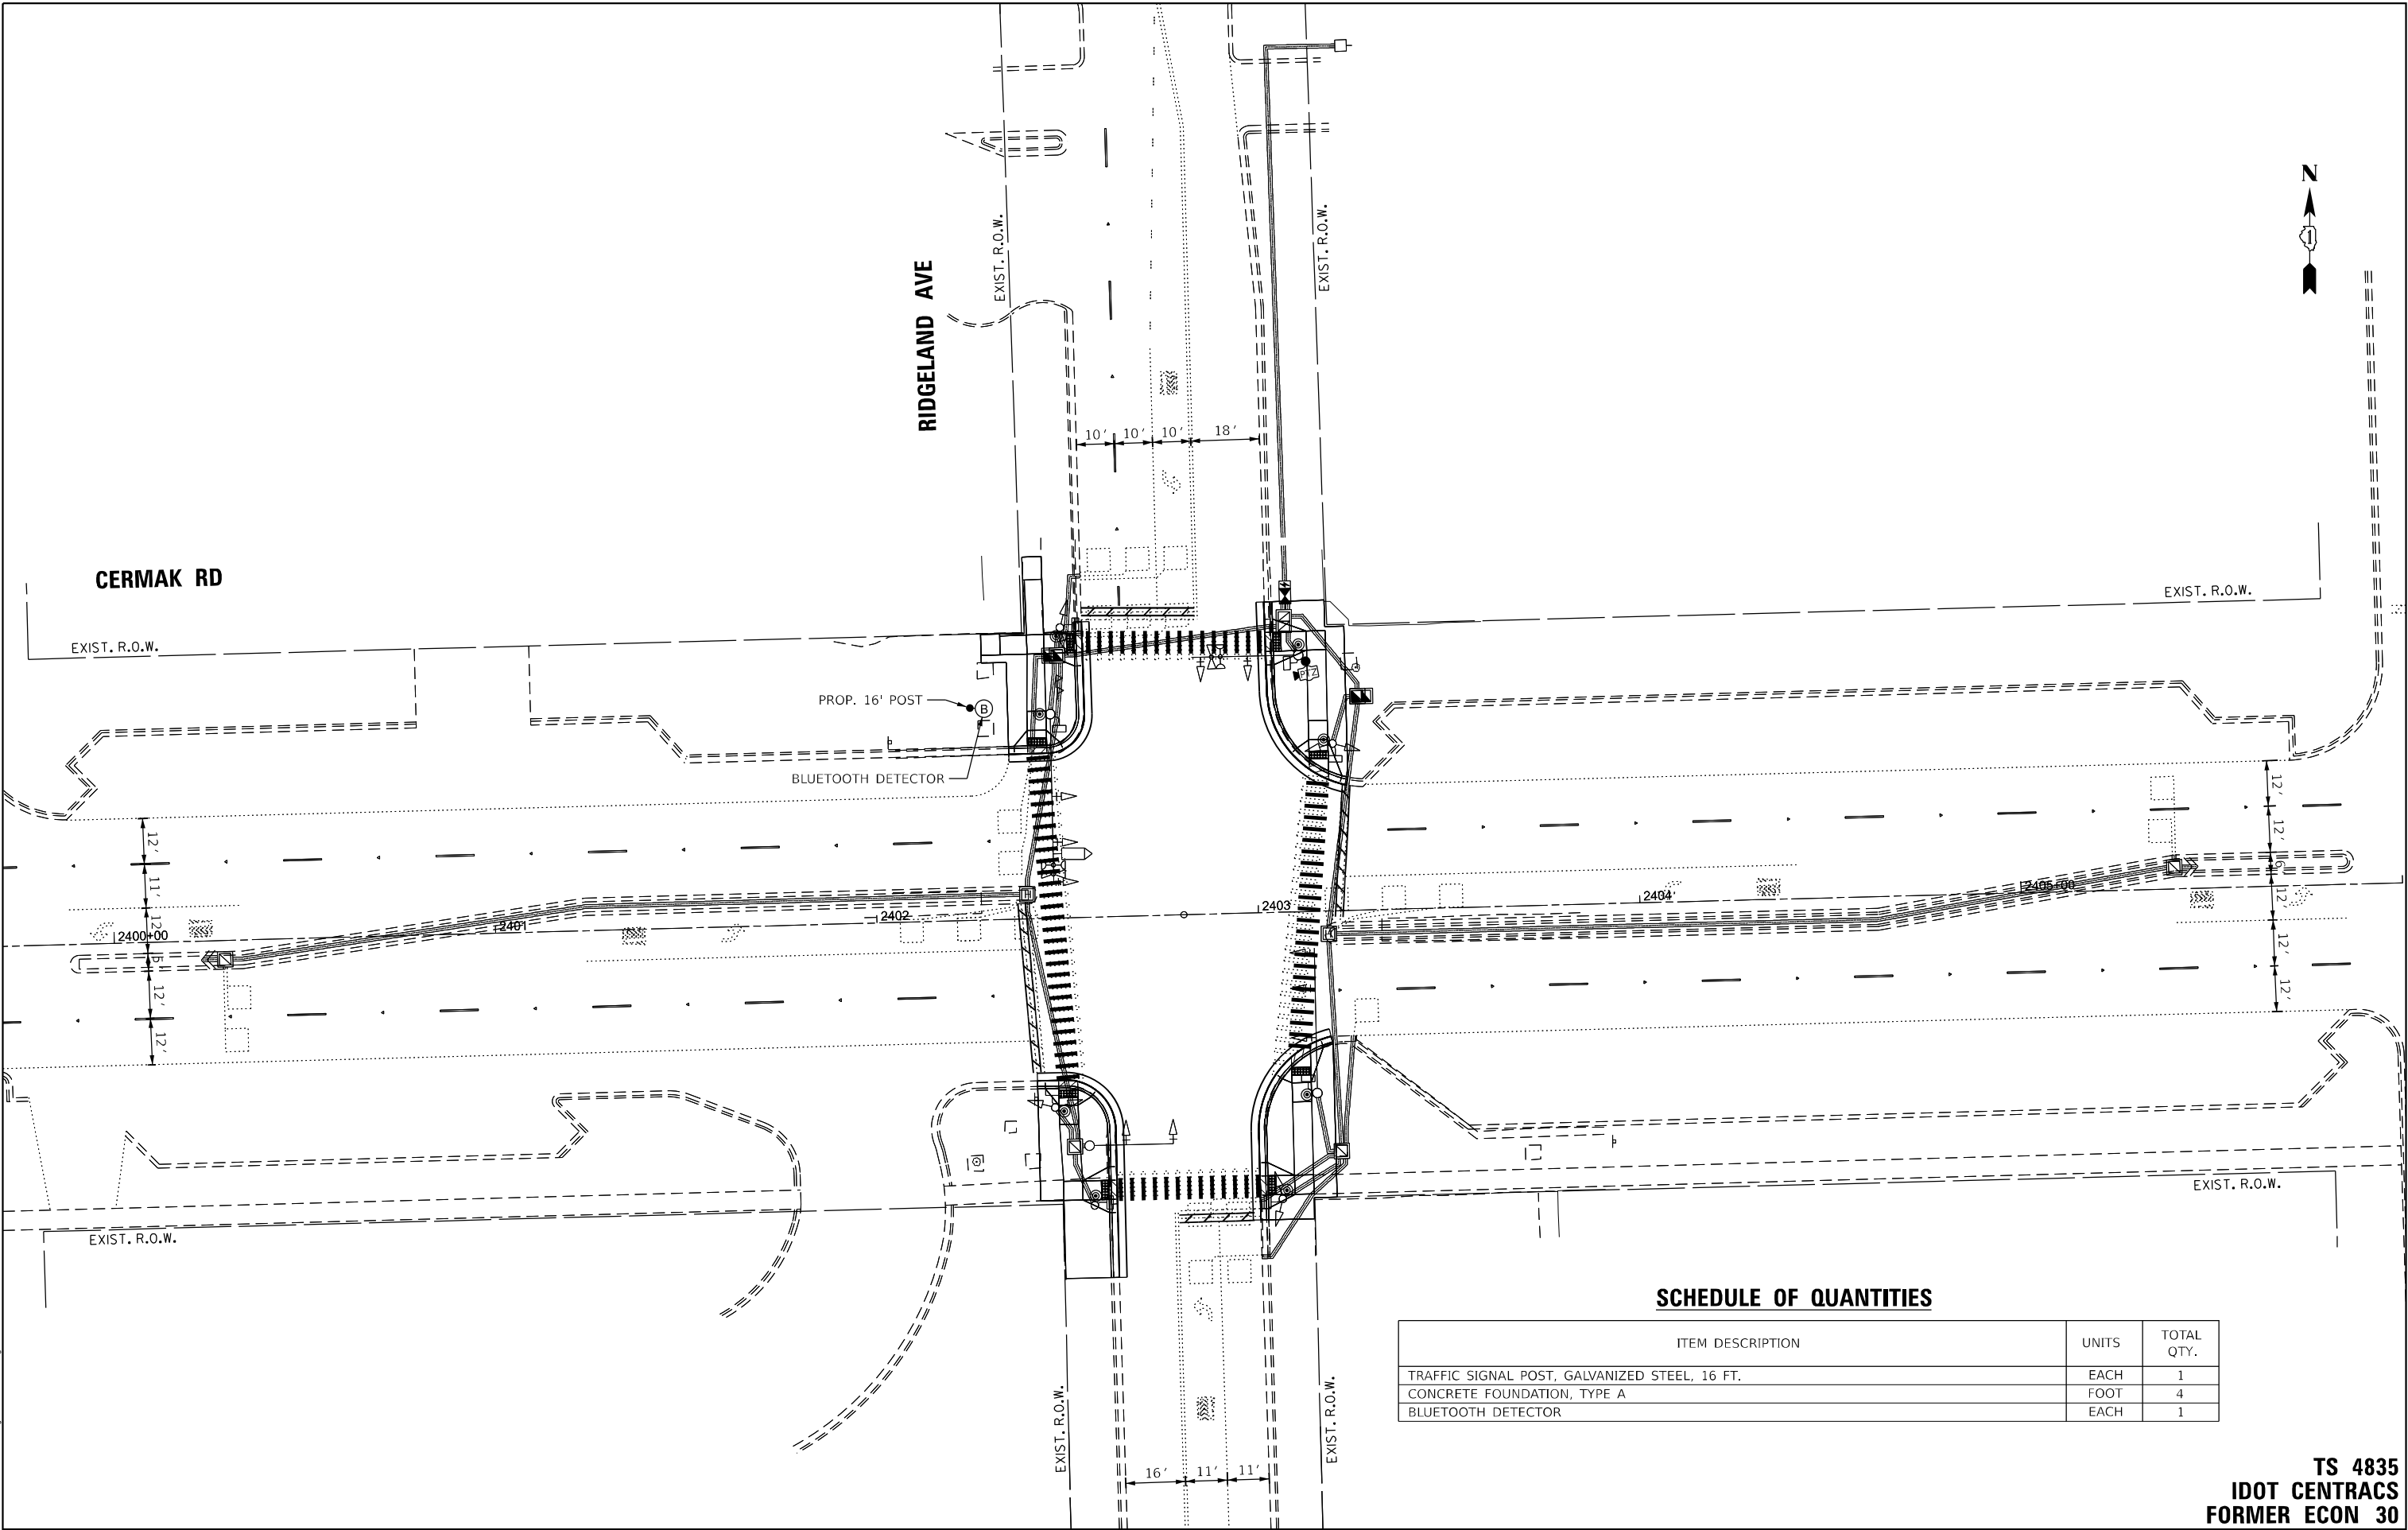



TS SHT NO. 190

MODEL NAME: D:\2023\2023-266-SUR\190 BIT Laramie Avenue.dgn

AMES Engineering, Inc.  
CONSULTING ENGINEERS  
6330 Belmont Road, Suite 4B  
Downers Grove, IL 60516

USER NAME = msomer  
PLOT SCALE = \$SCALE\$  
PLOT DATE = 03/19/2025

DESIGNED - TM  
DRAWN - TM, SR  
CHECKED - JAR  
DATE - 05/23/2024

REVISED -  
REVISED -  
REVISED -  
REVISED -


STATE OF ILLINOIS  
DEPARTMENT OF TRANSPORTATION

BLUETOOTH INSTALLATION PLAN  
CERMAK RD AND LARAMIE AVE

SCALE: 1" = 20' SHEET OF SHEETS STA. TO STA.

| F.A.U.<br>RTE.     | SECTION               | COUNTY      | TOTAL<br>SHEETS  | SHEET<br>NO. |
|--------------------|-----------------------|-------------|------------------|--------------|
| 1453               | 2020-266-SUR, SW & TS | COOK/DUPAGE | 492              | 338          |
| CONTRACT NO. 62N39 |                       |             |                  |              |
| ILLINOIS           |                       |             | FED. AID PROJECT |              |

TS 12785  
IDOT CENTRACS  
FORMER ECON 108

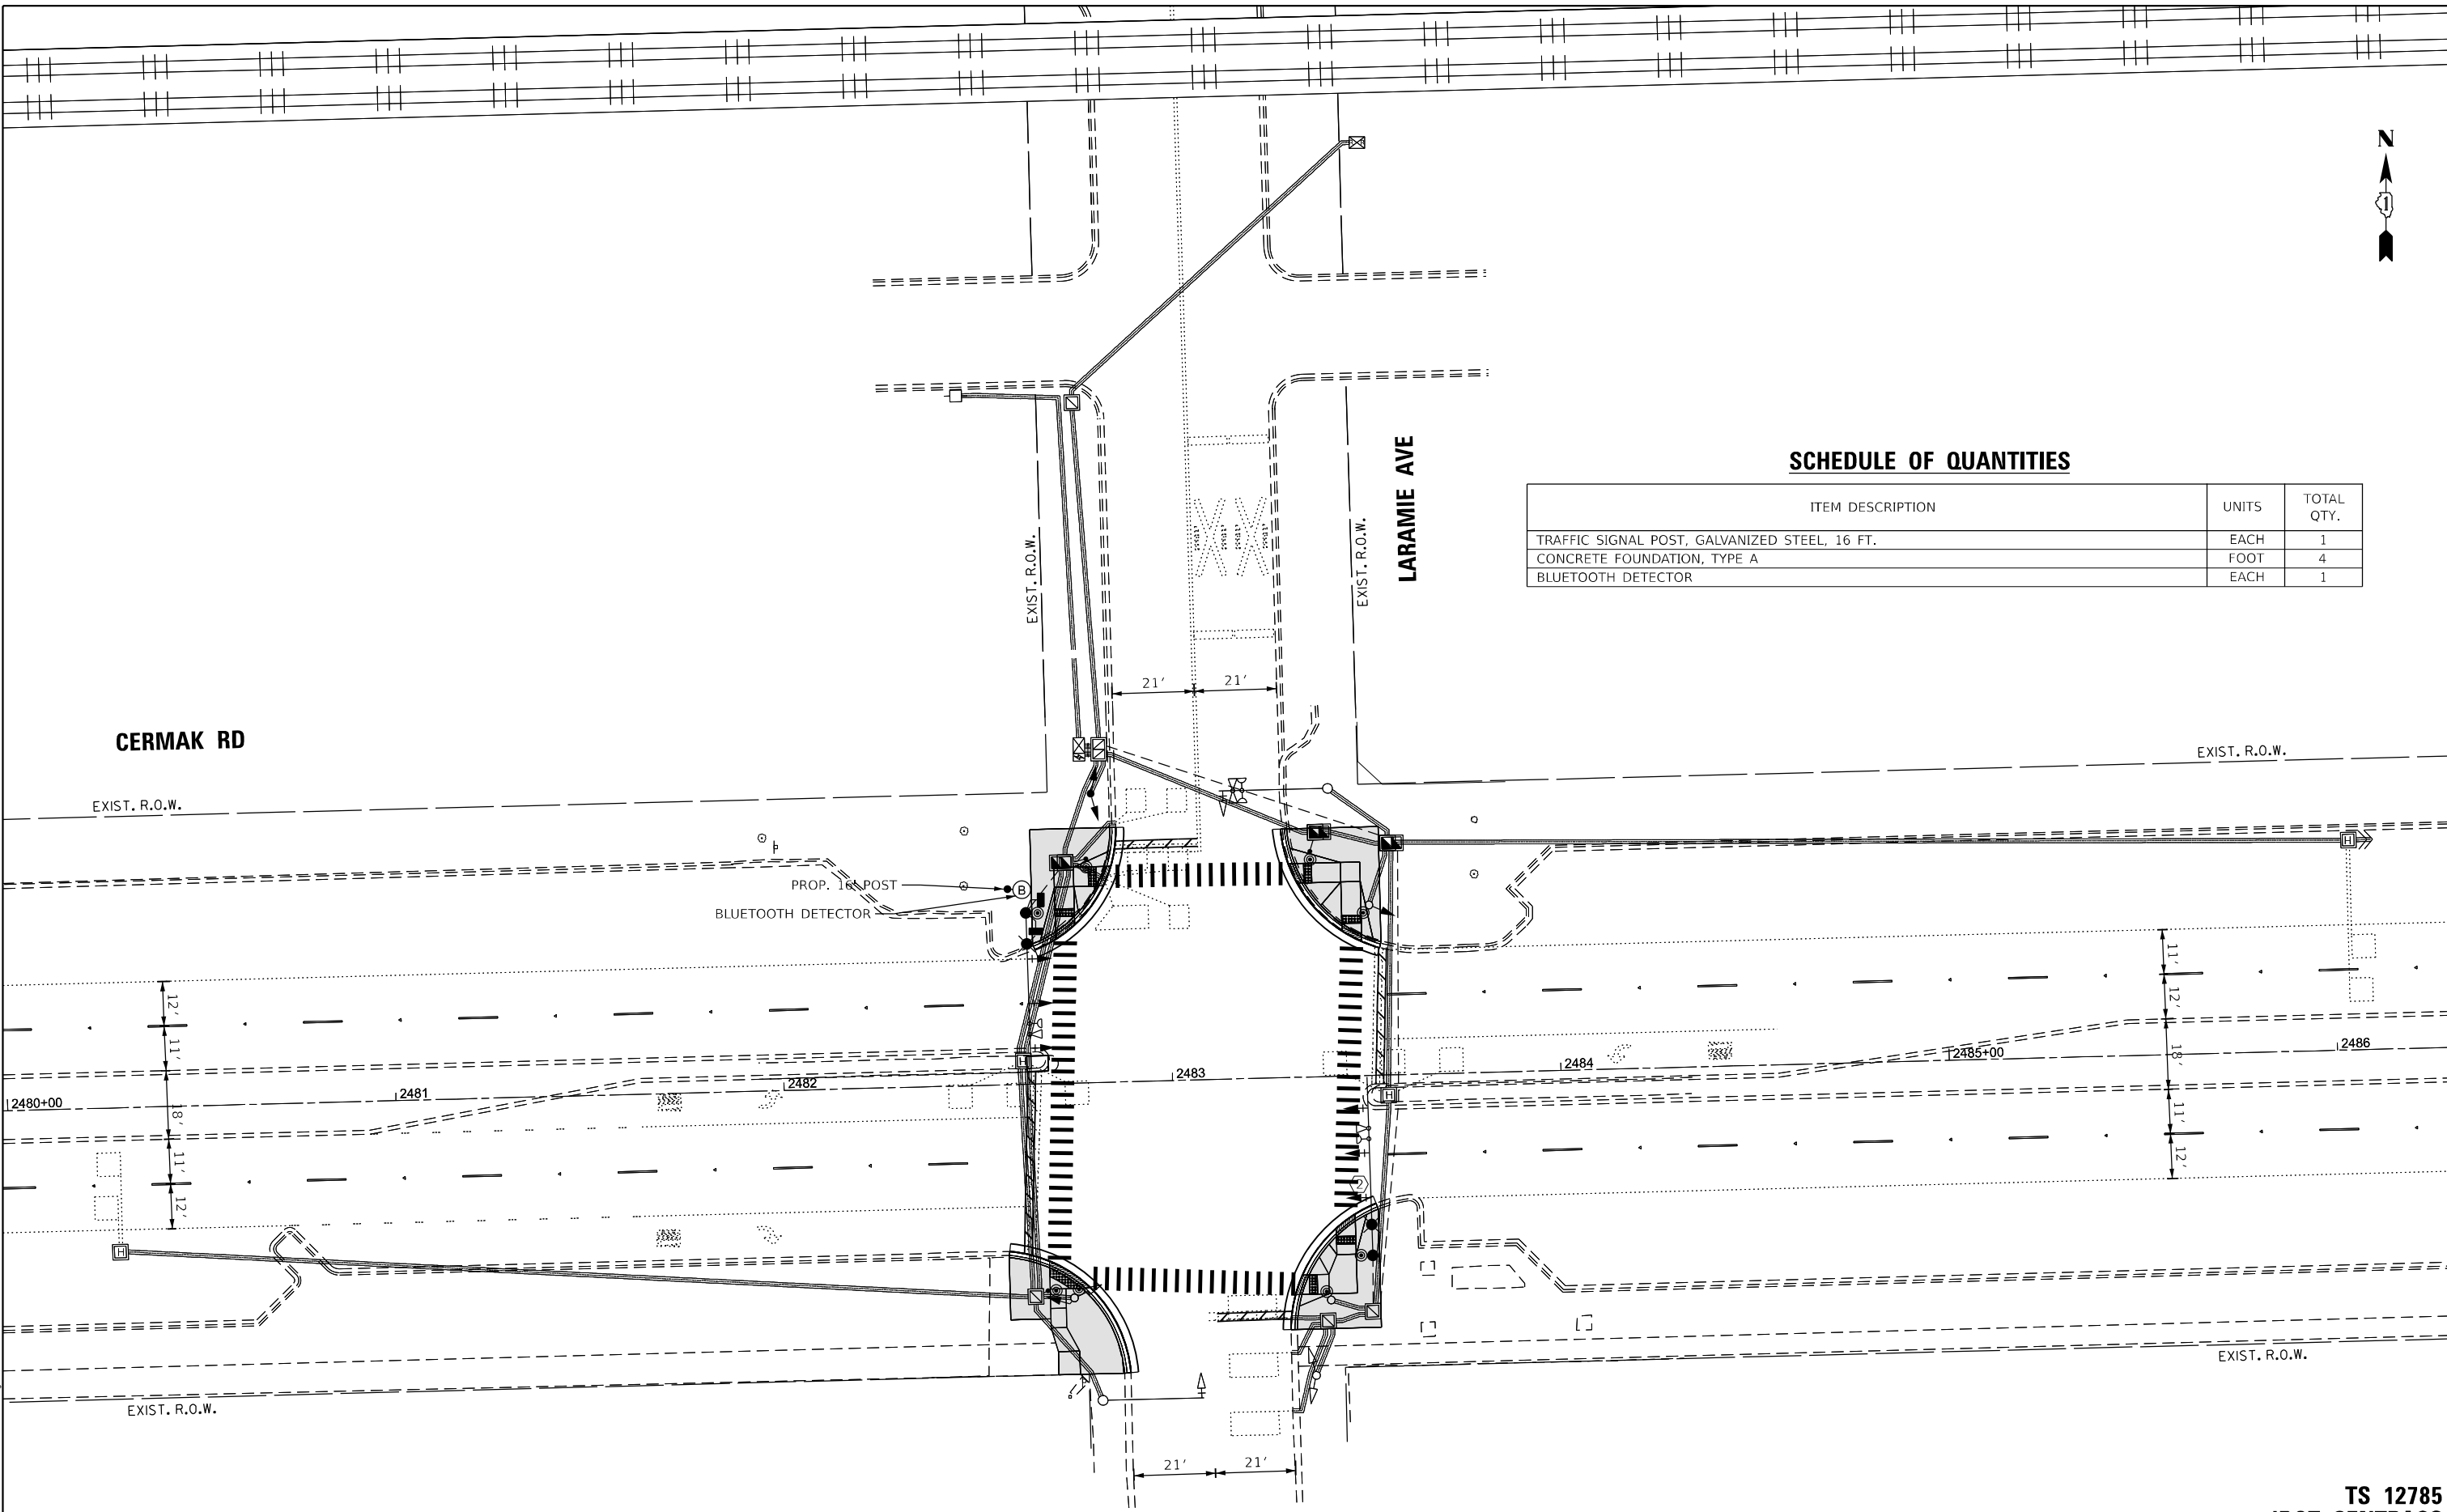

SCHEDULE OF QUANTITIES

| ITEM DESCRIPTION                              | UNITS | TOTAL QTY. |
|-----------------------------------------------|-------|------------|
| TRAFFIC SIGNAL POST, GALVANIZED STEEL, 16 FT. | EACH  | 1          |
| CONCRETE FOUNDATION, TYPE A                   | FOOT  | 4          |
| BLUETOOTH DETECTOR                            | EACH  | 1          |

TS SHT NO. 191

MODEL NAME: TS191  
FILE NAME: D:\2023\TS191\_BIT Cicero Avenue.dgn

AMES Engineering, Inc.  
CONSULTING ENGINEERS  
6330 Belmont Road, Suite 4B  
Downers Grove, IL 60516

|            |              |            |            |           |  |
|------------|--------------|------------|------------|-----------|--|
| USER NAME  | = msomer     | DESIGNED - | TM         | REVISED - |  |
|            |              | DRAWN -    | TM, SR     | REVISED - |  |
| PLOT SCALE | = \$SCALE\$  | CHECKED -  | JAR        | REVISED - |  |
| PLOT DATE  | = 03/19/2025 | DATE -     | 05/23/2024 | REVISED - |  |


STATE OF ILLINOIS  
DEPARTMENT OF TRANSPORTATION

BLUETOOTH INSTALLATION PLAN  
CERMAK RD AND IL RTE 50 (CICERO AVE)

SCALE: 1" = 20' SHEET OF SHEETS STA. TO STA.


| F.A.U. RTE.               | SECTION               | COUNTY      | TOTAL SHEETS | SHEET NO. |
|---------------------------|-----------------------|-------------|--------------|-----------|
| 1453                      | 2020-266-SUR, SW & TS | COOK/DUPAGE | 492          | 339       |
| CONTRACT NO. 62N39        |                       |             |              |           |
| ILLINOIS FED. AID PROJECT |                       |             |              |           |

TS 12770  
IDOT CENTRACS  
FORMER ECON 108

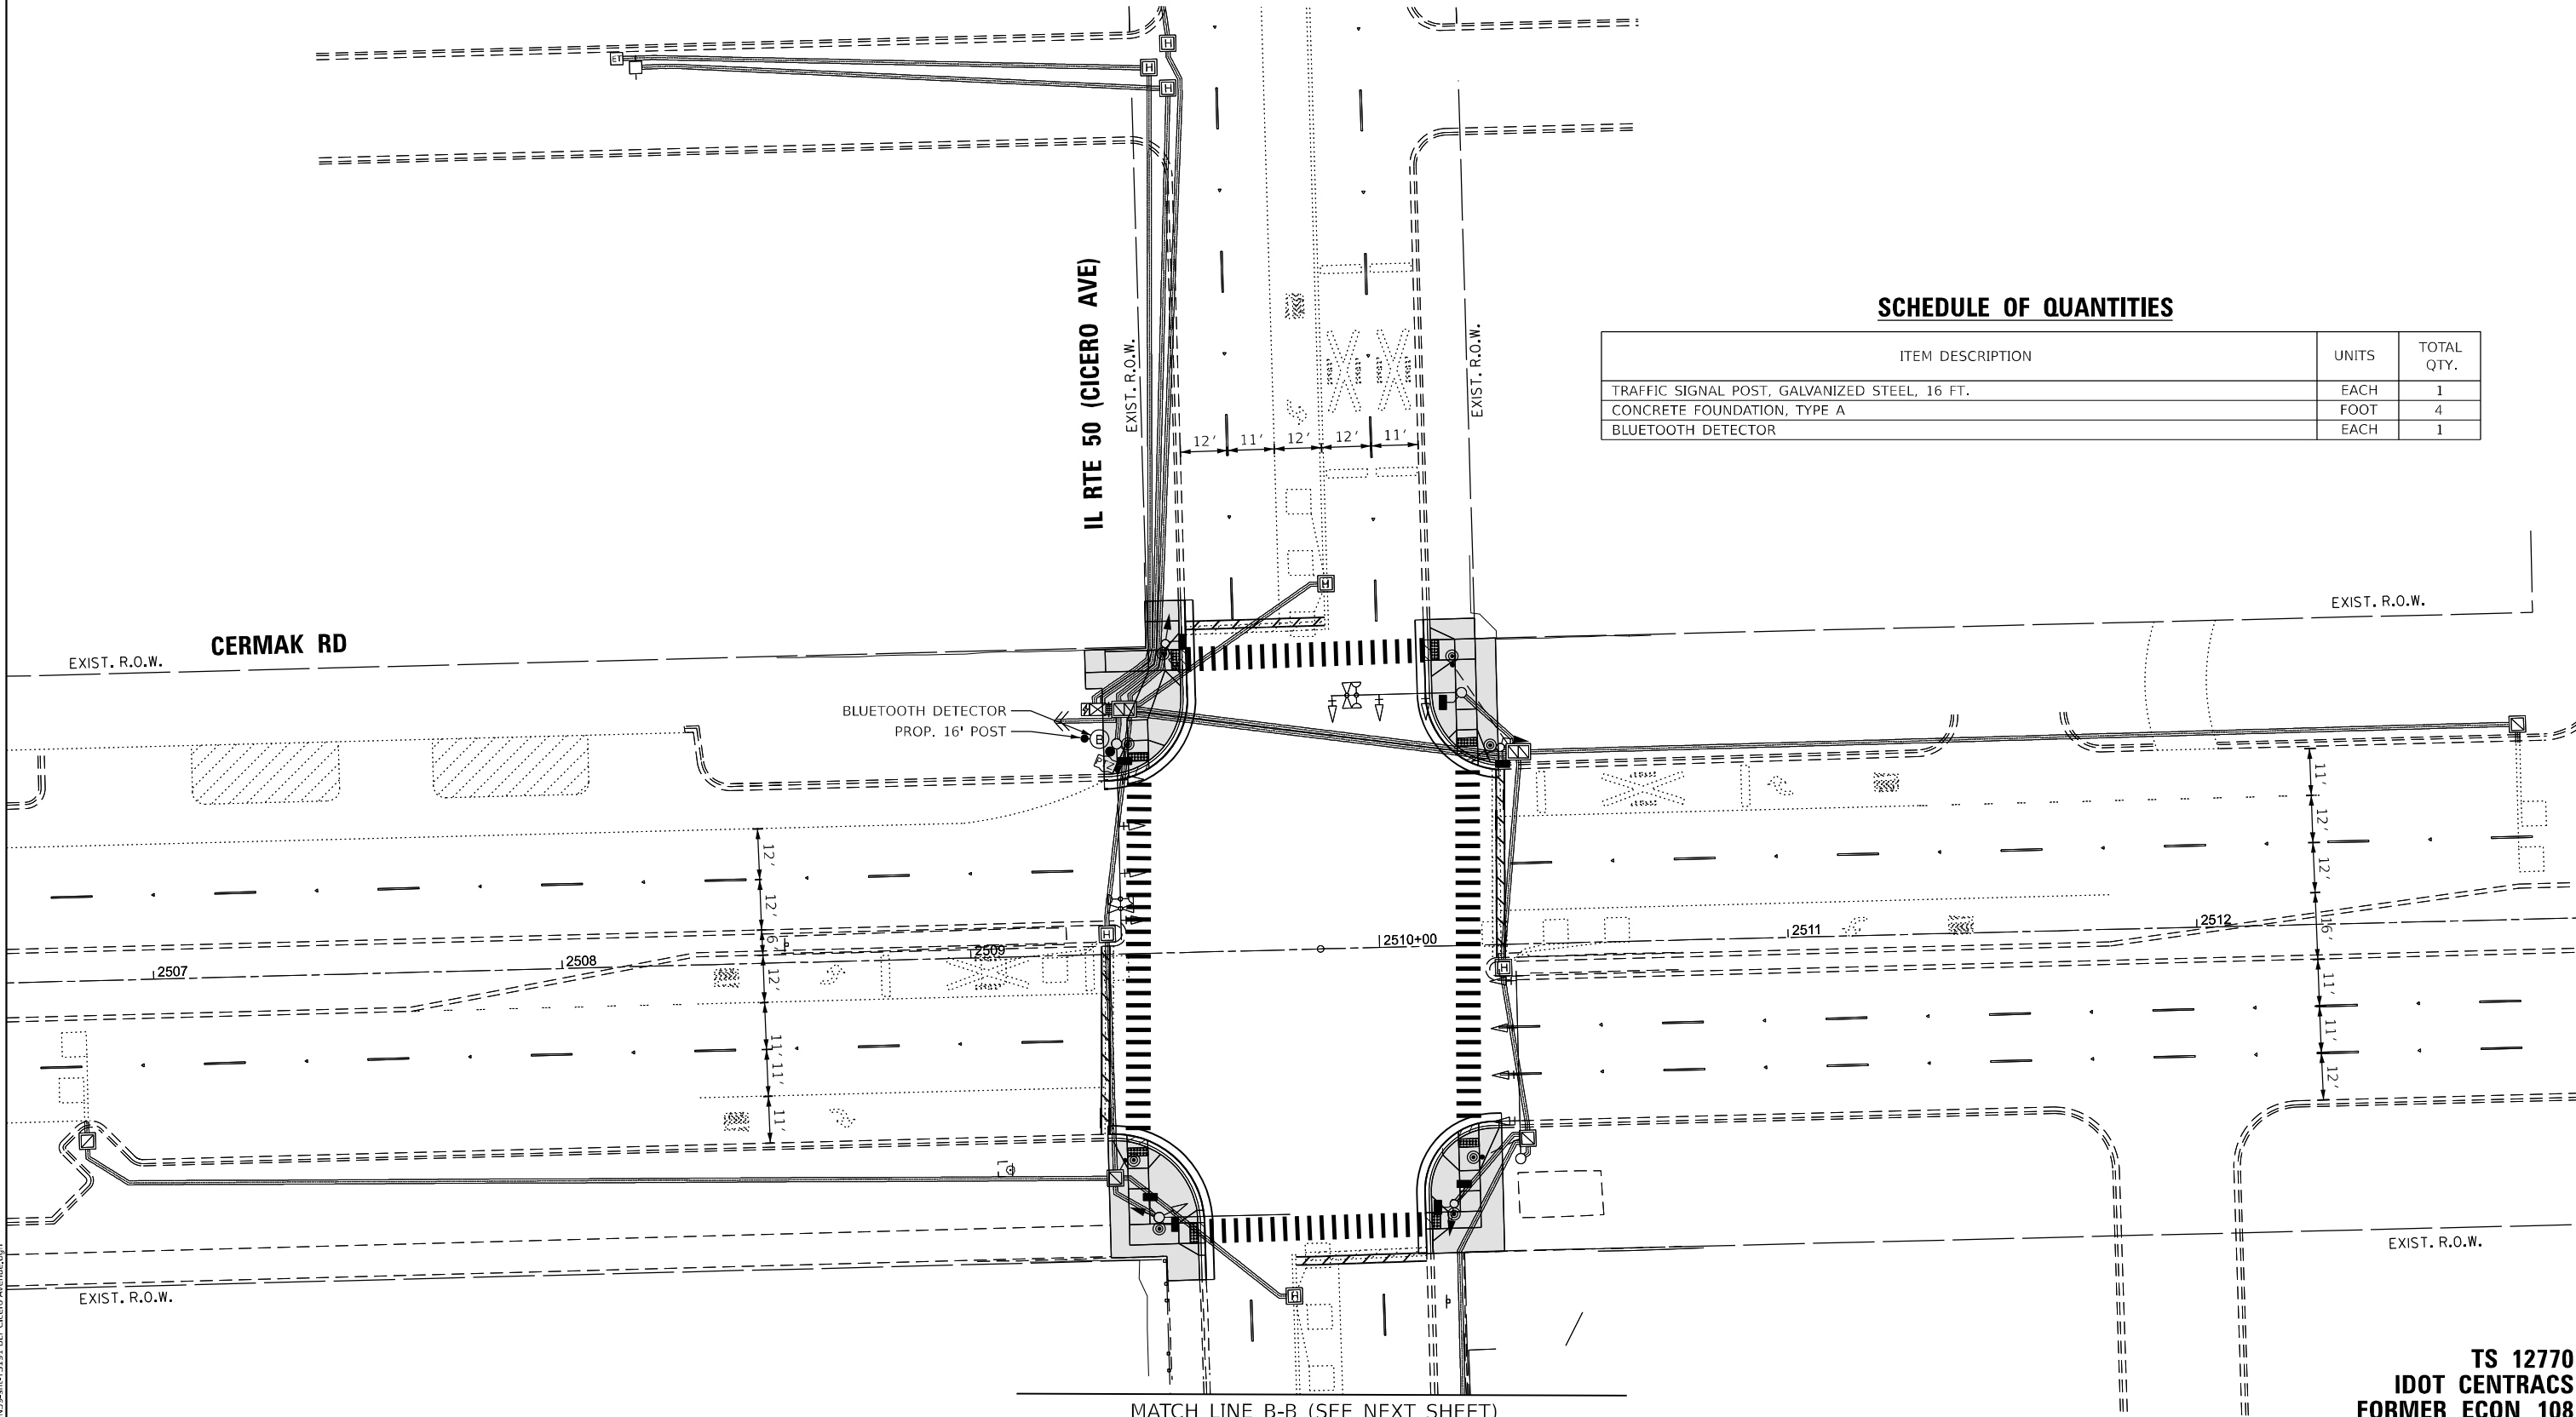

### SCHEDULE OF QUANTITIES


| ITEM DESCRIPTION                              | UNITS | TOTAL QTY. |
|-----------------------------------------------|-------|------------|
| TRAFFIC SIGNAL POST, GALVANIZED STEEL, 16 FT. | EACH  | 1          |
| CONCRETE FOUNDATION, TYPE A                   | FOOT  | 4          |
| BLUETOOTH DETECTOR                            | EACH  | 1          |

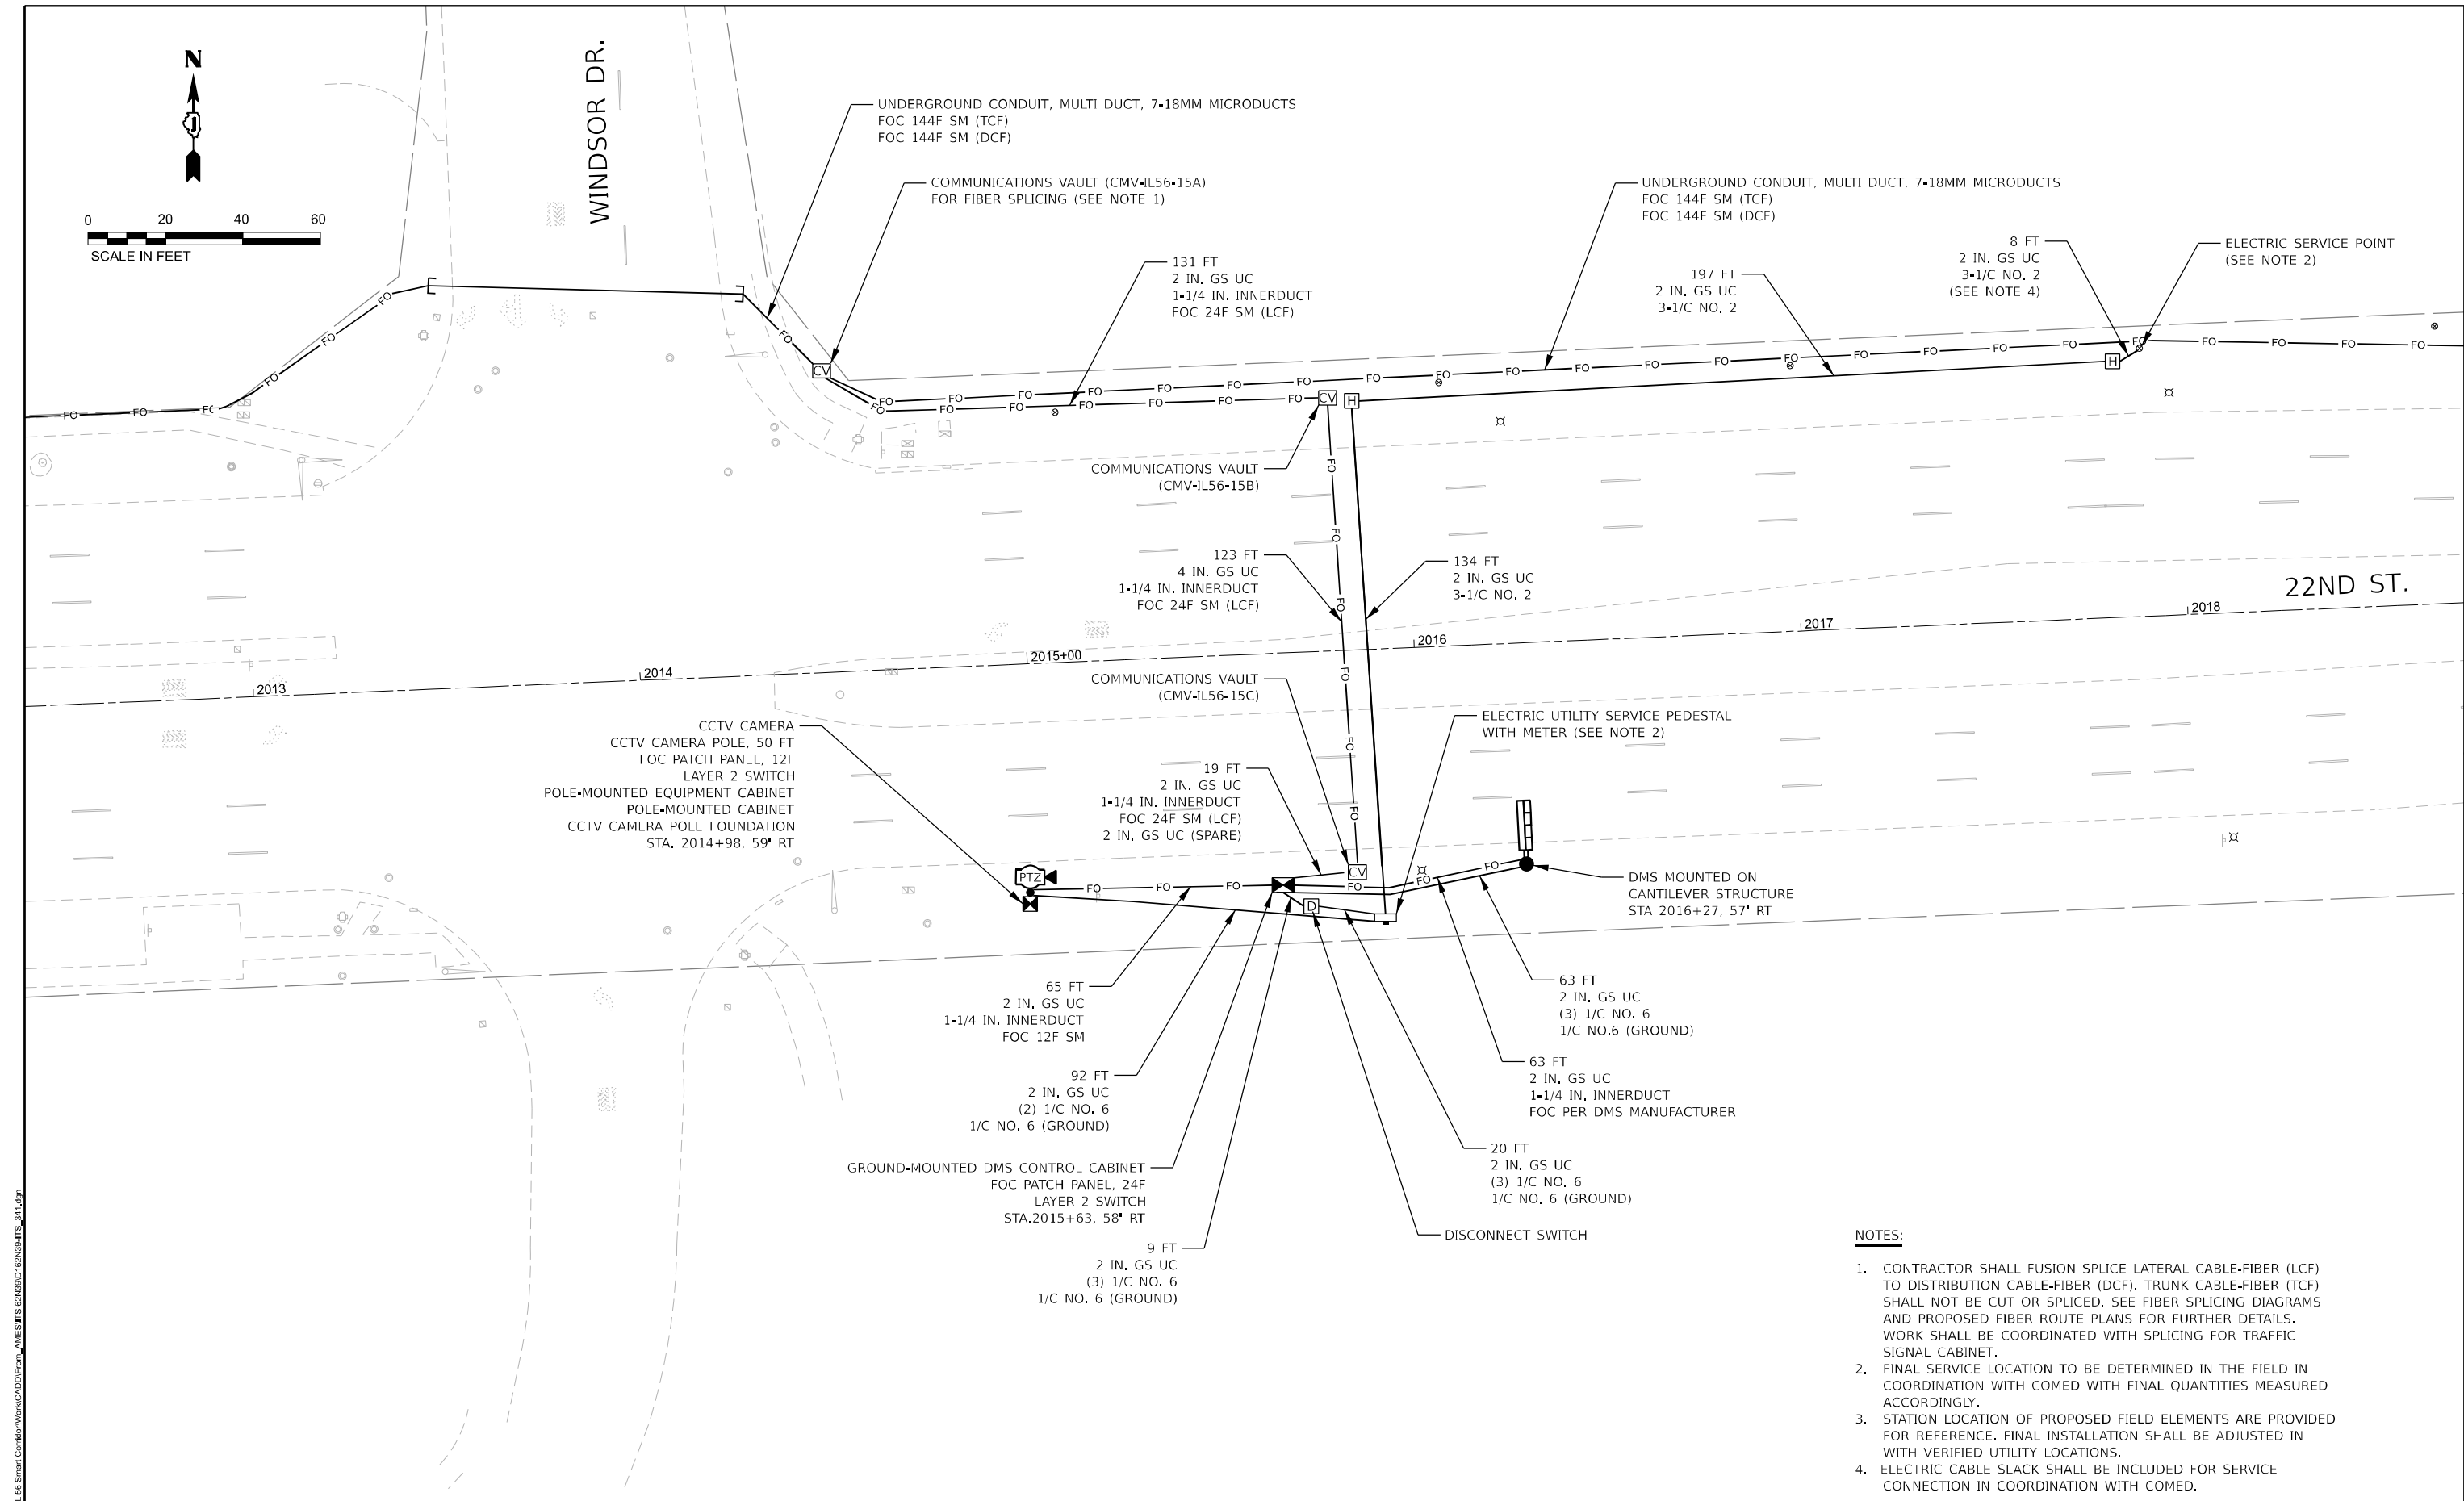

- NOTES:
- 1. CONTRACTOR SHALL FUSION SPlice LATERAL CABLE-FIBER (LCF) TO DISTRIBUTION CABLE-FIBER (DCF), TRUNK CABLE-FIBER (TCF) SHALL NOT BE CUT OR SPliced. SEE FIBER SPLICING DIAGRAMS AND PROPOSED FIBER ROUTE PLANS FOR FURTHER DETAILS. WORK SHALL BE COORDINATED WITH SPLICING FOR TRAFFIC SIGNAL CABINET.
  - 2. FINAL SERVICE LOCATION TO BE DETERMINED IN THE FIELD IN COORDINATION WITH COMED WITH FINAL QUANTITIES MEASURED ACCORDINGLY.
  - 3. STATION LOCATION OF PROPOSED FIELD ELEMENTS ARE PROVIDED FOR REFERENCE. FINAL INSTALLATION SHALL BE ADJUSTED IN WITH VERIFIED UTILITY LOCATIONS.
  - 4. ELECTRIC CABLE SLACK SHALL BE INCLUDED FOR SERVICE CONNECTION IN COORDINATION WITH COMED.





MODEL: D:\p1\116\116.dwg  
FILE NAME: 230624037.DOT 116.dwg  
SHEET: 341 OF 341  
DATE: 11/6/2024

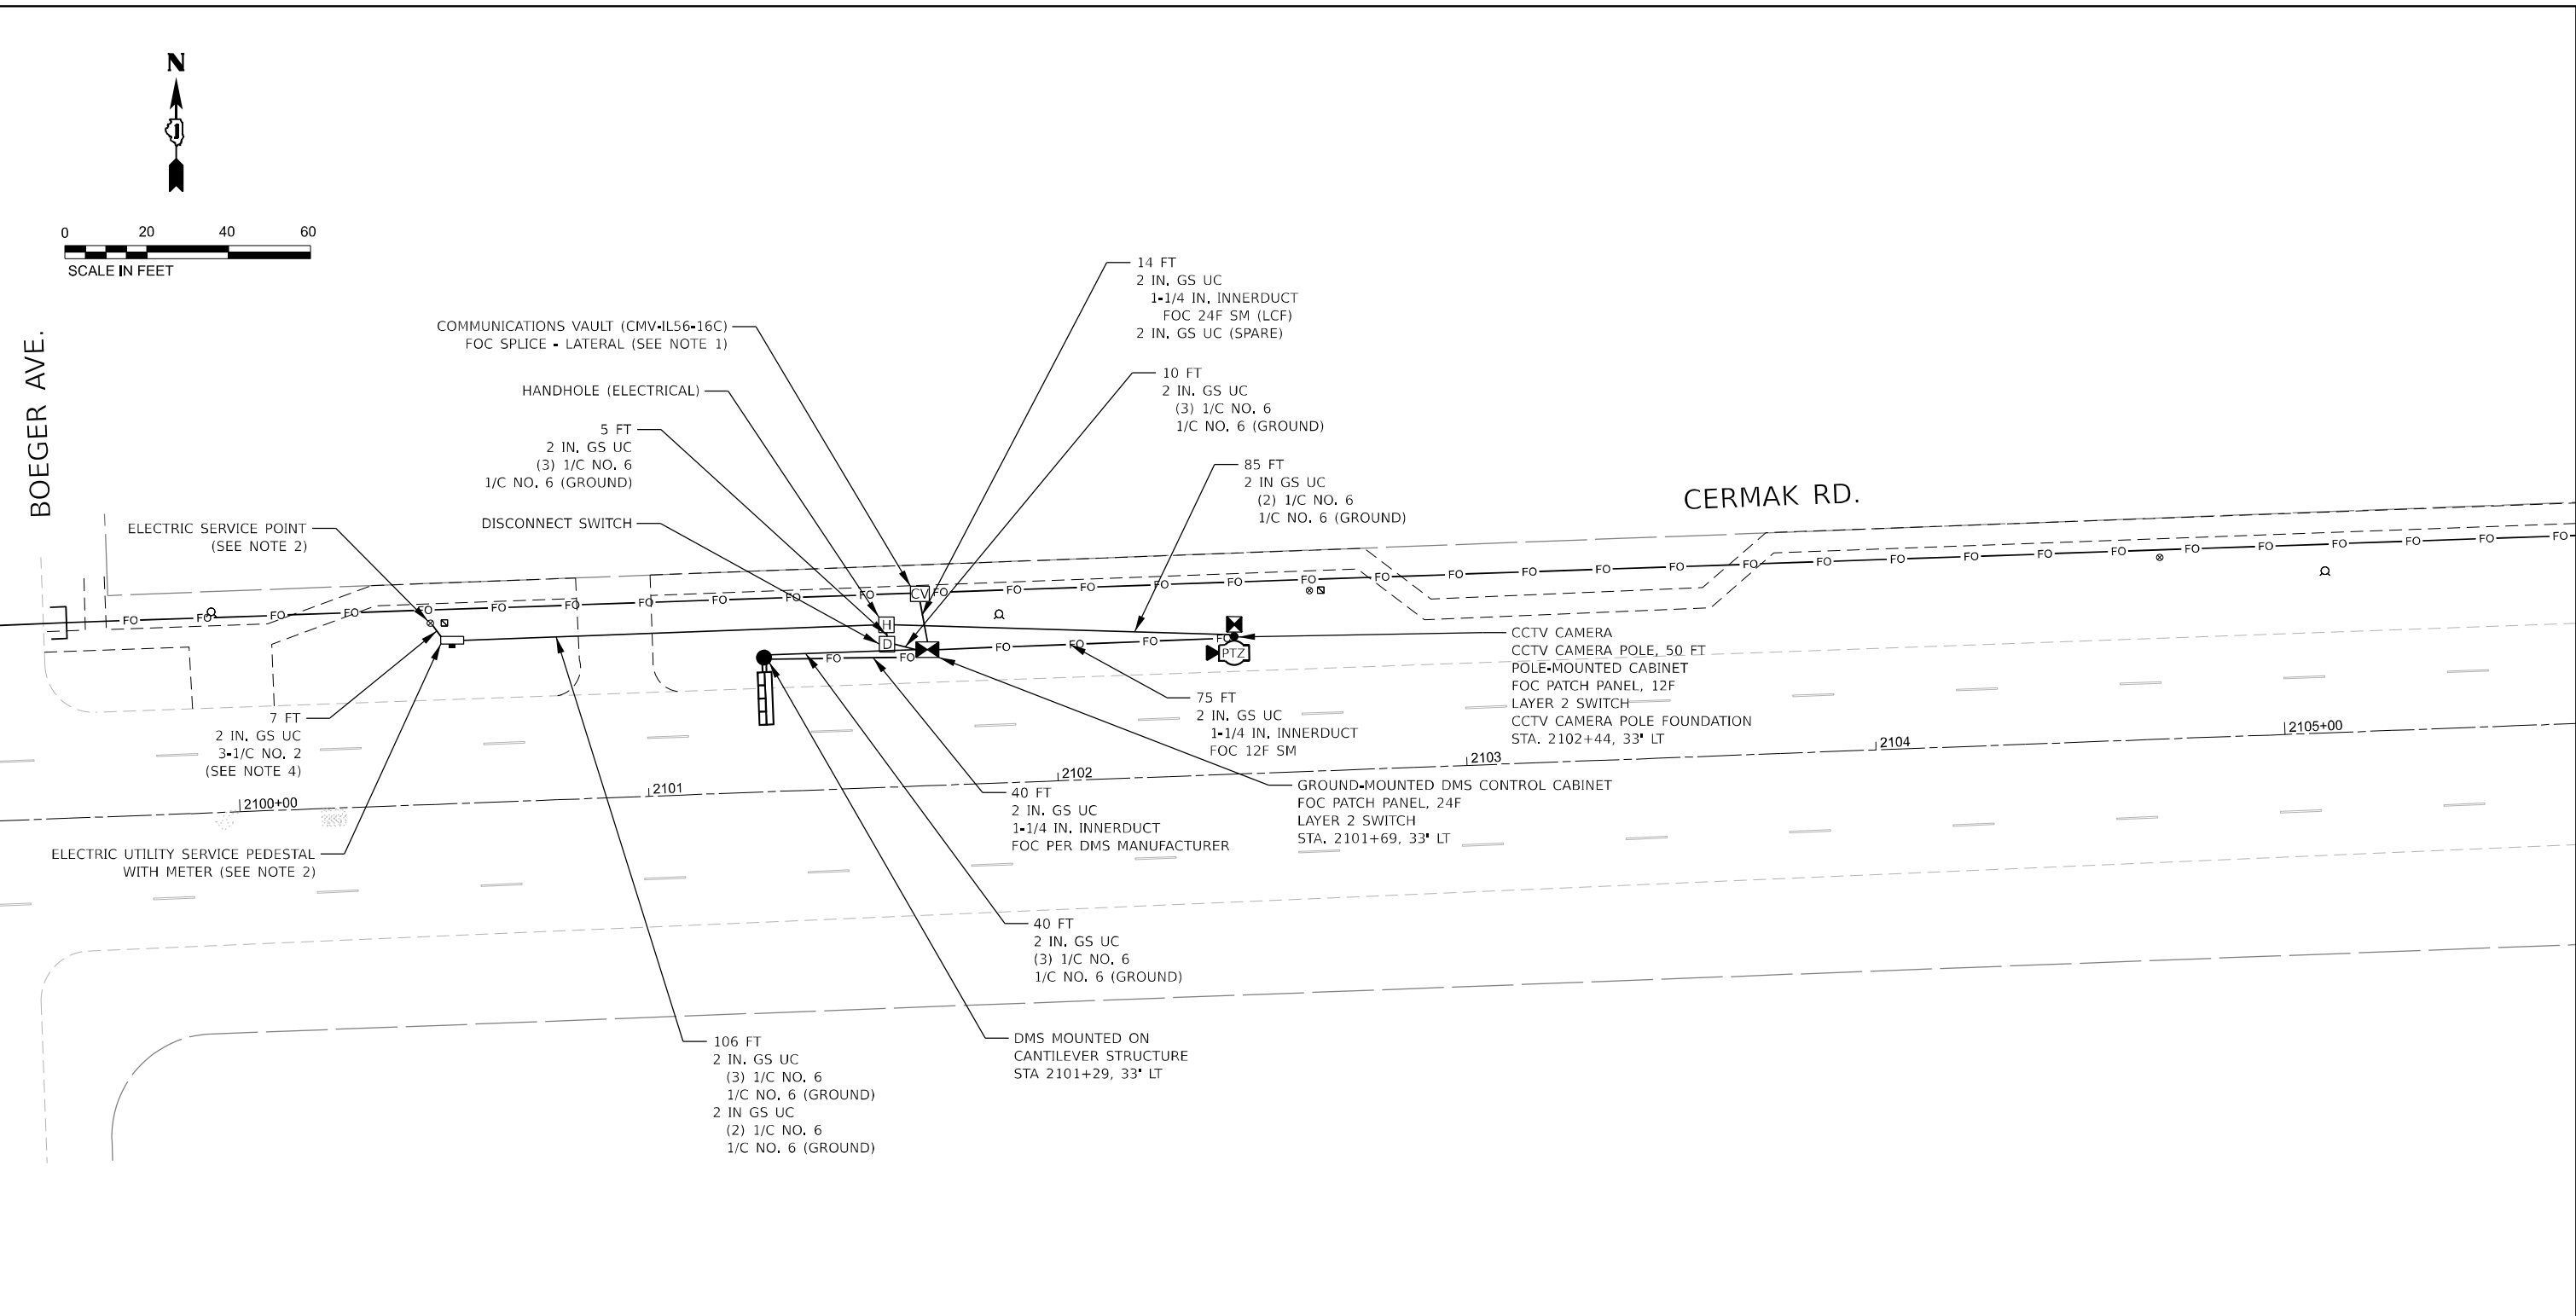


- NOTES:
- CONTRACTOR SHALL FUSION SPLICE LATERAL CABLE-FIBER (LCF) TO DISTRIBUTION CABLE-FIBER (DCF), TRUNK CABLE-FIBER (TCF) SHALL NOT BE CUT OR SPLICED, SEE FIBER SPLICING DIAGRAMS AND PROPOSED FIBER ROUTE PLANS FOR FURTHER DETAILS.
  - FINAL SERVICE LOCATION TO BE DETERMINED IN THE FIELD IN COORDINATION WITH COMED WITH FINAL QUANTITIES MEASURED ACCORDINGLY.
  - STATION LOCATION OF PROPOSED FIELD ELEMENTS ARE PROVIDED FOR REFERENCE. FINAL INSTALLATION SHALL BE ADJUSTED IN COORDINATION WITH VERIFIED UTILITY LOCATIONS.
  - ELECTRIC CABLE SLACK SHALL BE INCLUDED FOR SERVICE CONNECTION IN COORDINATION WITH COMED.



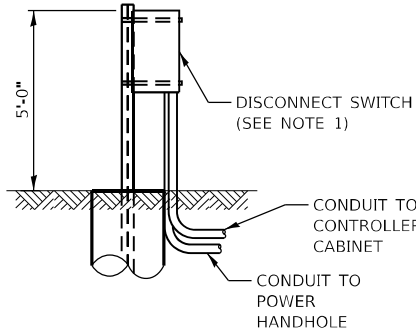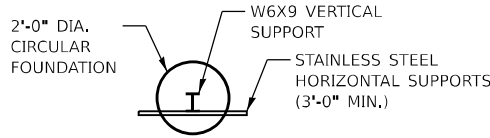

30A-2P NEMA 4X  
DISCONNECT MOUNTED  
ON SUPPORT DETAIL  
(NOT TO SCALE)

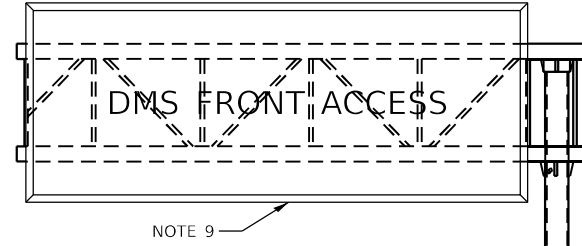

NOTE 9

1" DIA. FRE OR PVC COATED CONDUIT WITH 2/0 TINNED BARE STRANDED CABLE TO MASTER GROUND BUSBAR

DISCONNECT SWITCH NEMA 4X, UNFUSED 30A, 2P, 600V, LOCKABLE MOUNTED ON SUPPORT (SEE DETAIL THIS SHEET)

MASTER GROUND BUSBAR

GROUND MOUNTED DMS CONTROL CABINET

HH

CV

FIBER OPTIC COMMUNICATIONS VAULT

POWER HANDHOLE

2-2" CONDUIT (1) FOR SINGLE-MODE FIBER OPTIC CABLE (1) SPARE

2-2" CONDUIT 5'-0" FROM EDGE OF PAD (CAP AND SEAL FOR FUTURE USE)


GROUNDING ELECTRODE SYSTEM (REFER TO DMS GROUNDING DETAIL)

2" CONDUIT FOR POWER TO DISCONNECT SWITCH

2" CONDUIT FOR POWER TO DMS CABINET

2" CONDUIT FOR DMS DATA CONNECTION FROM DMS CONTROLLER (FIBER OPTIC CABLE PER DMS MANUFACTURER) (ADJACENT TO FOUNDATION)

2" CONDUITS FOR DMS POWER AND COMM

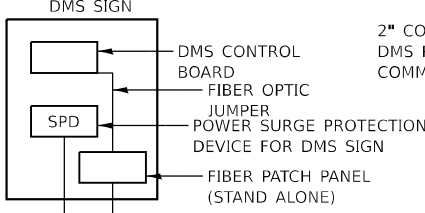

SPD

12 STRAND MMF OR SMF TO SIGN

DMS SIGN CONTROLLER

CAT 6 CABLE

POWER (120V)

I.P. RELAY

POWER

12VDC PS

POWER (120V)

UPS

FIBER PATCH PANEL (RACK MOUNTED)

24 STRAND SMF ITS CABLES

TO FIBER OPTIC COMMUNICATIONS VAULT SPICE

COMMUNICATION RISER  
(NOT TO SCALE)

| DMS CABINET - IP RELAY WIRING TABLE |                               |                 |            |                                 |            |
|-------------------------------------|-------------------------------|-----------------|------------|---------------------------------|------------|
| IP TERMINAL                         | DESCRIPTION                   | CONNECTION FROM |            | CONNECTION TO                   |            |
|                                     |                               | DEVICE          | CONNECTION | DEVICE                          | CONNECTION |
| 1                                   | DMS LOAD SHEDDING RELAY<br>CB | IP_RELAY        | 12VDC (+)  | CB                              | CB1A       |
|                                     |                               | CB1B            | IP_RELAY   | 3 COMM                          |            |
|                                     |                               | IP_RELAY        | 3 NC       | LOAD SHED RELAY                 | COIL (+)   |
|                                     |                               | SPLICE BLOCK    | 120 V      | IP_RELAY                        | NC         |
| 2                                   | DMS CONTROLLER                | IP_RELAY        | 4 NC       | POWER OUTLET #1 (COMMUNICATION) | HOT        |
|                                     |                               |                 |            |                                 |            |
| 3                                   | RESERVED FOR CCTV CAMERA      |                 |            |                                 |            |
| *                                   | REMAINING TERMINALS - OPEN    |                 |            |                                 |            |
|                                     |                               |                 |            |                                 |            |
|                                     |                               |                 |            |                                 |            |

GENERAL NOTES:

- FURNISH AND INSTALL SERVICE DISCONNECT ON W6X9 SUPPORT.
- THIS IS A DIAGRAMMATIC SCHEMATIC, ALL BREAKERS AND LOAD CENTERS SHALL BE SIZED AND WIRED AS PER MANUFACTURER RECOMMENDATIONS.
- ENTIRE COMPLETED SYSTEM SHALL BE GROUNDED AND BONDED IN ACCORDANCE WITH MOTOROLA R56 MANUAL AND THE APPLICABLE ARTICLES OF SECTION 250 OF THE NATIONAL ELECTRICAL CODE.
- ALL UNDERGROUND CONDUITS SHALL BE COILABLE NON-METALLIC CONDUIT (CNC) AND ABOVE GRADE CONDUITS SHALL BE PVC-COATED RIGID GALVANIZED STEEL (PRGS) UNLESS OTHERWISE INDICATED ON THE PLANS, COUPLERS SHALL BE USED WHEN TRANSITIONING FROM CNC TO PRGS.
- MOUNT CLAMPS ON 5'-0" ON CENTER MOUNTING. HARDWARE SHALL BE USED AS PER CONDUIT MANUFACTURER RECOMMENDATION.
- CONTRACTOR SHALL SUPPLY AND INSTALL CABLE REDUCER LUGS WHERE SIZE OF CABLE ENTERING THE DISCONNECT IS MORE THAN RECOMMENDED SIZE DUE TO VOLTAGE DROP.
- CONTRACTOR SHALL WIRE THE DMS CABINET AS PER MANUFACTURER RECOMMENDATIONS AND INDUSTRY STANDARDS, USING THIS SCHEMATIC AS GUIDANCE ONLY.
- THE COM (COMMON) CONTACT AND NC (NORMALLY CLOSED) CONTACT ON RELAY CONTACTS OF DIN RELAY SHALL FOLLOW THE TABLE ABOVE.
- REFER TO STRUCTURAL PLAN SHEETS FOR OVERHEAD SIGN STRUCTURE CANTILEVER TYPE STRUCTURE DETAILS.
- TRANSFORMER SHALL BE FURNISHED BY UTILITY COMPANY. FOUNDATION AND TRANSFORMER GROUNDING BY CONTRACTOR SHALL BE IN ACCORDANCE WITH UTILITY COMPANY REQUIREMENTS AND MUST BE TIED INTO DMS SITE GROUNDING ELECTRODE SYSTEM.
- FIBER PATCH PANEL IN DMS SIGN HOUSING SHALL BE A FACTORY TERMINATED UNIT WITH A 12-STRAND PIGTAIL CONNECTING TO RACK MOUNTED FIBER PATCH PANEL IN DMS CONTROLLER CABINET.

POWER WIRING SCHEMATIC FOR 100A PANEL,  
120 / 240V LOAD CENTER OF DMS CABINET  
(NOT TO SCALE)

MODEL: MTS-103  
FILE NAME: Z669037.DOT  
66 Smart Conduit WorkCADD From AMES/ITS 62N39.DWG 343.dgn



|            |           |          |            |         |   |
|------------|-----------|----------|------------|---------|---|
| USER NAME  | USERS     | DESIGNED | YJ         | REVISED | - |
|            |           | DRAWN    | MT         | REVISED | - |
| PLOT SCALE | SSCALE\$  | CHECKED  | RCB        | REVISED | - |
| PLOT DATE  | 11/6/2024 | DATE     | 11-22-2024 | REVISED | - |



STATE OF ILLINOIS  
DEPARTMENT OF TRANSPORTATION

|                                          |         |    |        |
|------------------------------------------|---------|----|--------|
| DMS CABINET POWER<br>22ND ST./CERMAK RD. |         |    |        |
| SCALE: N,T,S,                            | SHEET 1 | OF | SHEETS |
| STA.                                     | TO STA. |    |        |

|                    |                       |             |              |           |
|--------------------|-----------------------|-------------|--------------|-----------|
| F.A.P. RTE.        | SECTION               | COUNTY      | TOTAL SHEETS | SHEET NO. |
| 365                | 2020-265-SUR, SW & TS | DUPAGE/COOK | 492          | 342       |
| CONTRACT NO. 62N39 |                       |             |              |           |
| ILLINOIS           | FED. AND PROJECT      |             |              |           |

ITS-03

MODEL: MITS-1105  
FILE NAME: Z669037.DOT  
56 Smart Connector Work/CADD From AMES/ITS 62N39/01/2024/ITS\_344.dgn

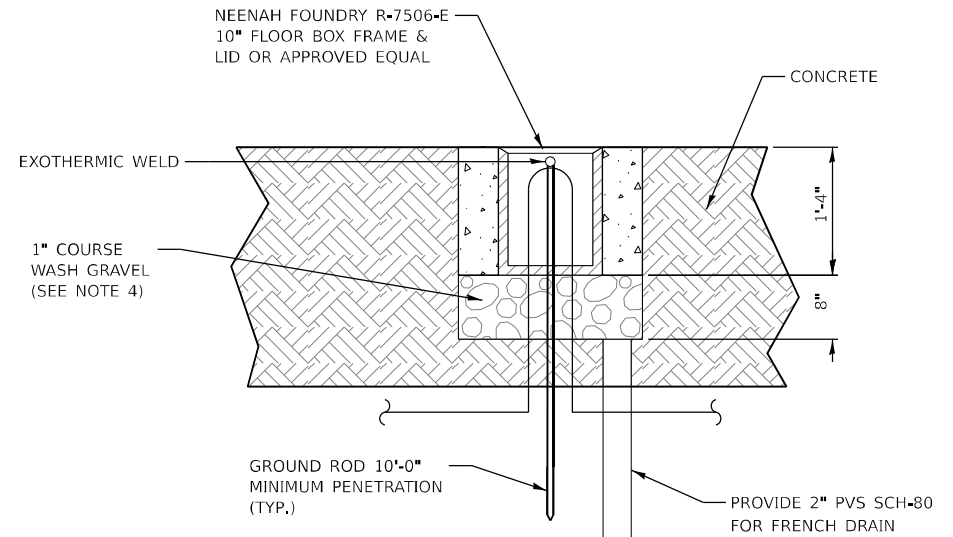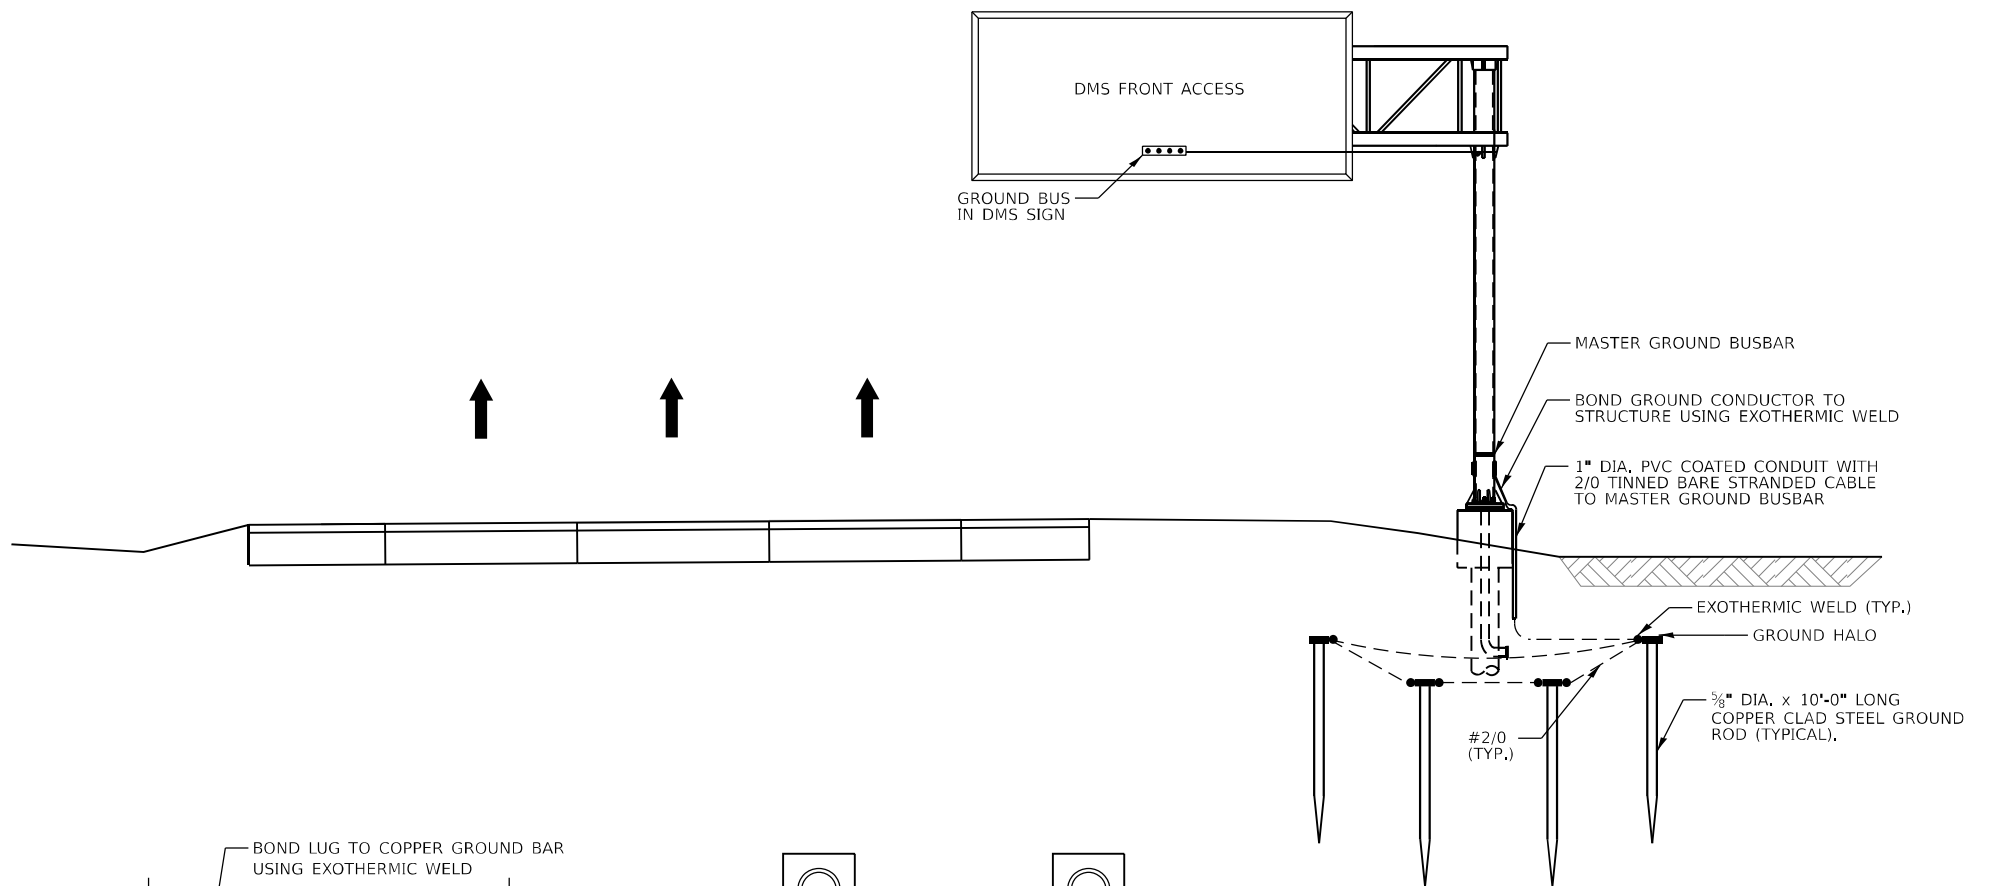

**GROUND WELL ELEVATION DETAIL**  
N.T.S.

**NOTES:**

- GROUNDING SYSTEM SHALL BE PLACED WITHIN IDOT RIGHT-OF-WAY.
- GROUND MOUNTED CONTROL CABINET SHALL BE PLACED UP STREAM OF THE STRUCTURE AT THE LOCATION SHOWN ON THE PLAN VIEW.
- INSTALL MARKER TAPE DIRECTLY ABOVE GROUNDING ELECTRODES AND CONDUCTORS.
- CA-11, A QUALITY, IN ACCORDANCE WITH SSRBC 1004.
- QUANTITY OF GROUND RODS CONNECTED TO GROUNDING ELECTRODE CONDUCTOR SHALL BE ADJUSTED AS REQUIRED UNTIL RESISTANCE TO GROUND IS 5 OHMS OR LESS. FOR DEVICE AND POWER SERVICE LOCATIONS, IF ADDITIONAL GROUND ROD ELECTRODES ARE REQUIRED IN ORDER TO ACHIEVE REQUIRED RESISTANCE THEY SHALL RADIATE OUT FROM EXISTING GROUND ROD ELECTRODES. THESE SHALL BE CONNECTED WITH #2/0 TINNED BARE STRANDED CONDUCTOR, AND SHALL BE 20' FROM CONNECTED GROUND ROD. ALL COMMUNICATION EQUIPMENT GROUNDING SITES SHALL BE TESTED FOR RESISTANCE TO GROUND USING THE THREE-POINT FALL-OF-POTENTIAL TEST PER ANSI/IEEE STD 81.
- GROUND RODS SHALL NOT BE ROUTED THROUGH FOUNDATIONS.
- GROUND RODS SHALL BE INSTALLED IN GROUND WELLS IN FINISHED GRADE.
- ALL EQUIPMENT GROUNDS SHALL BE PROPERLY CONNECTED TO A CHASSIS: ALL PAINT AND OTHER COATINGS, INCLUDING GALVANIZATION, SHALL BE REMOVED PRIOR TO TERMINATION OF A GROUND, AFTER THE GROUND IS TERMINATED A NON-OXIDIZING COATING SHALL BE PAINTED OVER THE EXPOSED METAL SURFACES.
- ALL METALLIC MEMBERS OF THE DMS STRUCTURE AND THE DMS SIGN WITHIN 6 FEET OF EACH OTHER SHALL BE BONDED TOGETHER. WELDS SHALL BE CONSIDERED AN ACCEPTABLE BONDING METHOD, U-BOLT CONNECTIONS SHALL NOT BE CONSIDERED AN ACCEPTABLE BONDING METHOD.
- AT LEAST AN 8 INCH MINIMUM BENDING RADIUS SHALL BE MAINTAINED ON ALL GROUNDING ELECTRODE CONDUCTORS, THE ANGLE OF ANY BENDING SHALL NOT BE LESS THAN 90 DEGREES.
- GROUNDING CONDUCTORS SHALL ALWAYS ROUTE AS STRAIGHT AS POSSIBLE.
- THE QUANTITY OF GROUNDING ELECTRODE CONDUCTORS CONNECTED TO A GROUND ROD ELECTRODE SHALL BE LIMITED TO THREE.
- WHENEVER POSSIBLE, GROUND ROD ELECTRODES SHALL BE INSTALLED NO CLOSER THAN 11' FROM A FOUNDATION.
- EVERY ELECTRIC CABLE ENTERING OR LEAVING A DMS ENCLOSURE, THE DMS CONTROLLER, OR THE CCTV ELECTRONICS ENCLOSURE SHALL BE PROTECTED WITH A SURGE PROTECTION DEVICE.

**ITS-04**



|            |             |          |              |         |   |
|------------|-------------|----------|--------------|---------|---|
| USER NAME  | ■ SUSERS    | DESIGNED | - YJ         | REVISED | - |
| DRAWN      | - MT        | REVISED  | -            |         |   |
| PLOT SCALE | ■ SS CALES  | CHECKED  | - RCB        | REVISED | - |
| PLOT DATE  | ■ 11/6/2024 | DATE     | - 11-22-2024 | REVISED | - |

**STATE OF ILLINOIS  
DEPARTMENT OF TRANSPORTATION**

**DMS GROUNDING  
22ND ST./CERMAK RD.**

SCALE: N.T.S. SHEET 1 OF SHEETS STA. TO STA.

| F.A.P. RTE.               | SECTION               | COUNTY      | TOTAL SHEETS | SHEET NO. |
|---------------------------|-----------------------|-------------|--------------|-----------|
| 365                       | 2020-265-SUR. SW & TS | DUPAGE/COOK | 492          | 343       |
| CONTRACT NO. 62N39        |                       |             |              |           |
| ILLINOIS FED. AID PROJECT |                       |             |              |           |

MODEL: MTS-1108  
FILE NAME: Z669097.DOT  
56 Smart Condition Work CADD From AMES/ITS 62N339D162N39ATS\_345.dgn





|            |             |            |              |           |  |
|------------|-------------|------------|--------------|-----------|--|
| USER NAME  | • SUSER\$   | DESIGNED - | YJ           | REVISED - |  |
|            |             | DRAWN -    | MT           | REVISED - |  |
| PLOT SCALE | • \$SCALE\$ | CHECKED -  | RCB          | REVISED - |  |
| PLOT DATE  | • 11/6/2024 | DATE       | - 11-22-2024 | REVISED - |  |

STATE OF ILLINOIS  
DEPARTMENT OF TRANSPORTATION

DMS CABINET COMMUNICATIONS FOUNDATION (1 OF 2)  
22ND ST./CERMAK RD.

SCALE: N,T,S, SHEET 1 OF SHEETS STA. TO STA.

|                           |                       |             |              |           |
|---------------------------|-----------------------|-------------|--------------|-----------|
| F.A.P. RTE.               | SECTION               | COUNTY      | TOTAL SHEETS | SHEET NO. |
| 365                       | 2020-265-SUR, SW & TS | DUPAGE/COOK | 492          | 344       |
| CONTRACT NO. 62N39        |                       |             |              |           |
| ILLINOIS FED. AID PROJECT |                       |             |              |           |

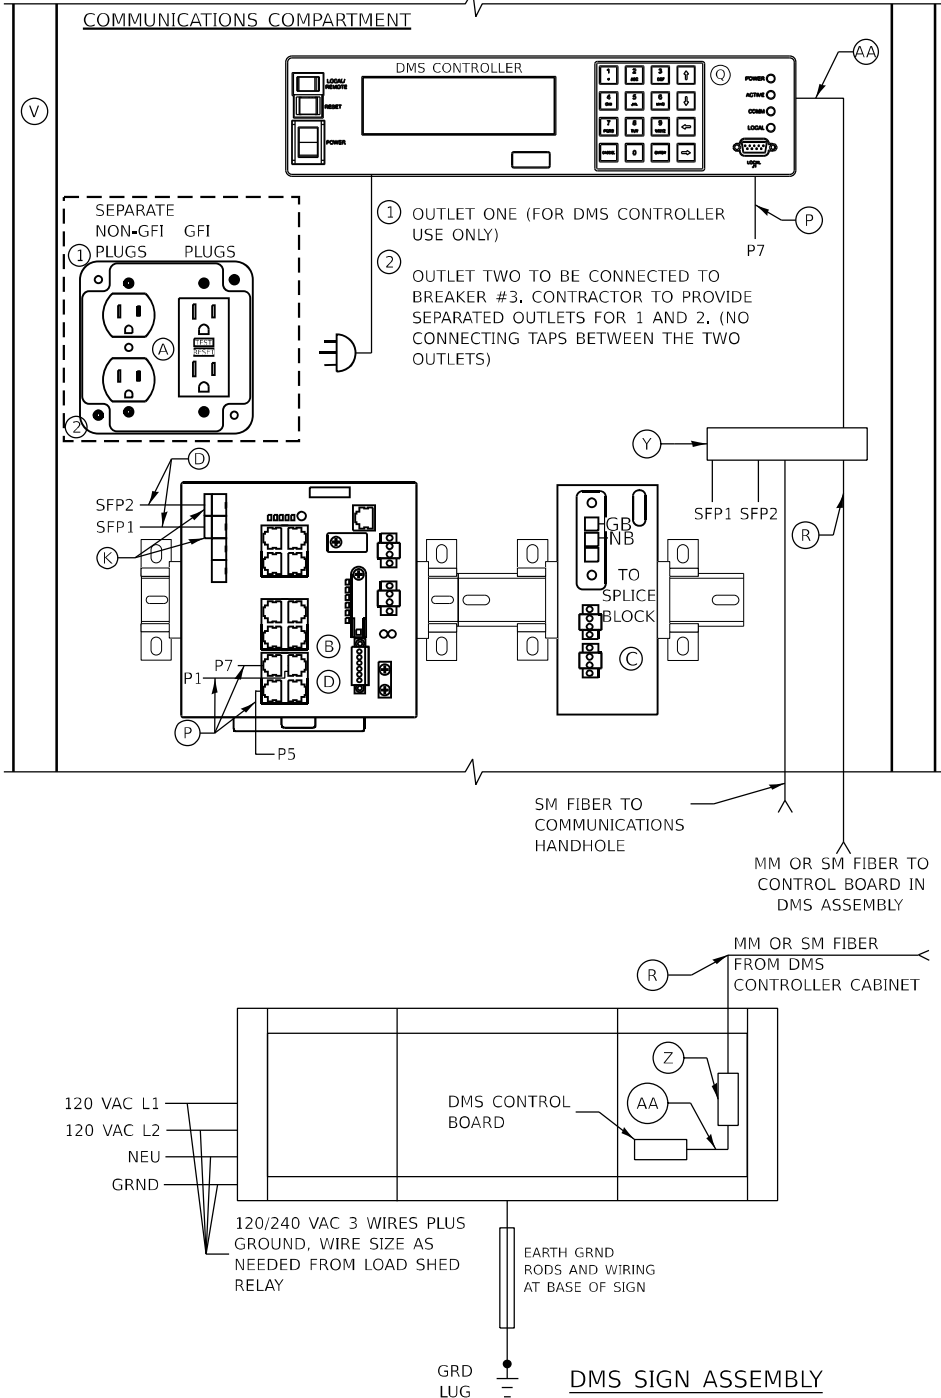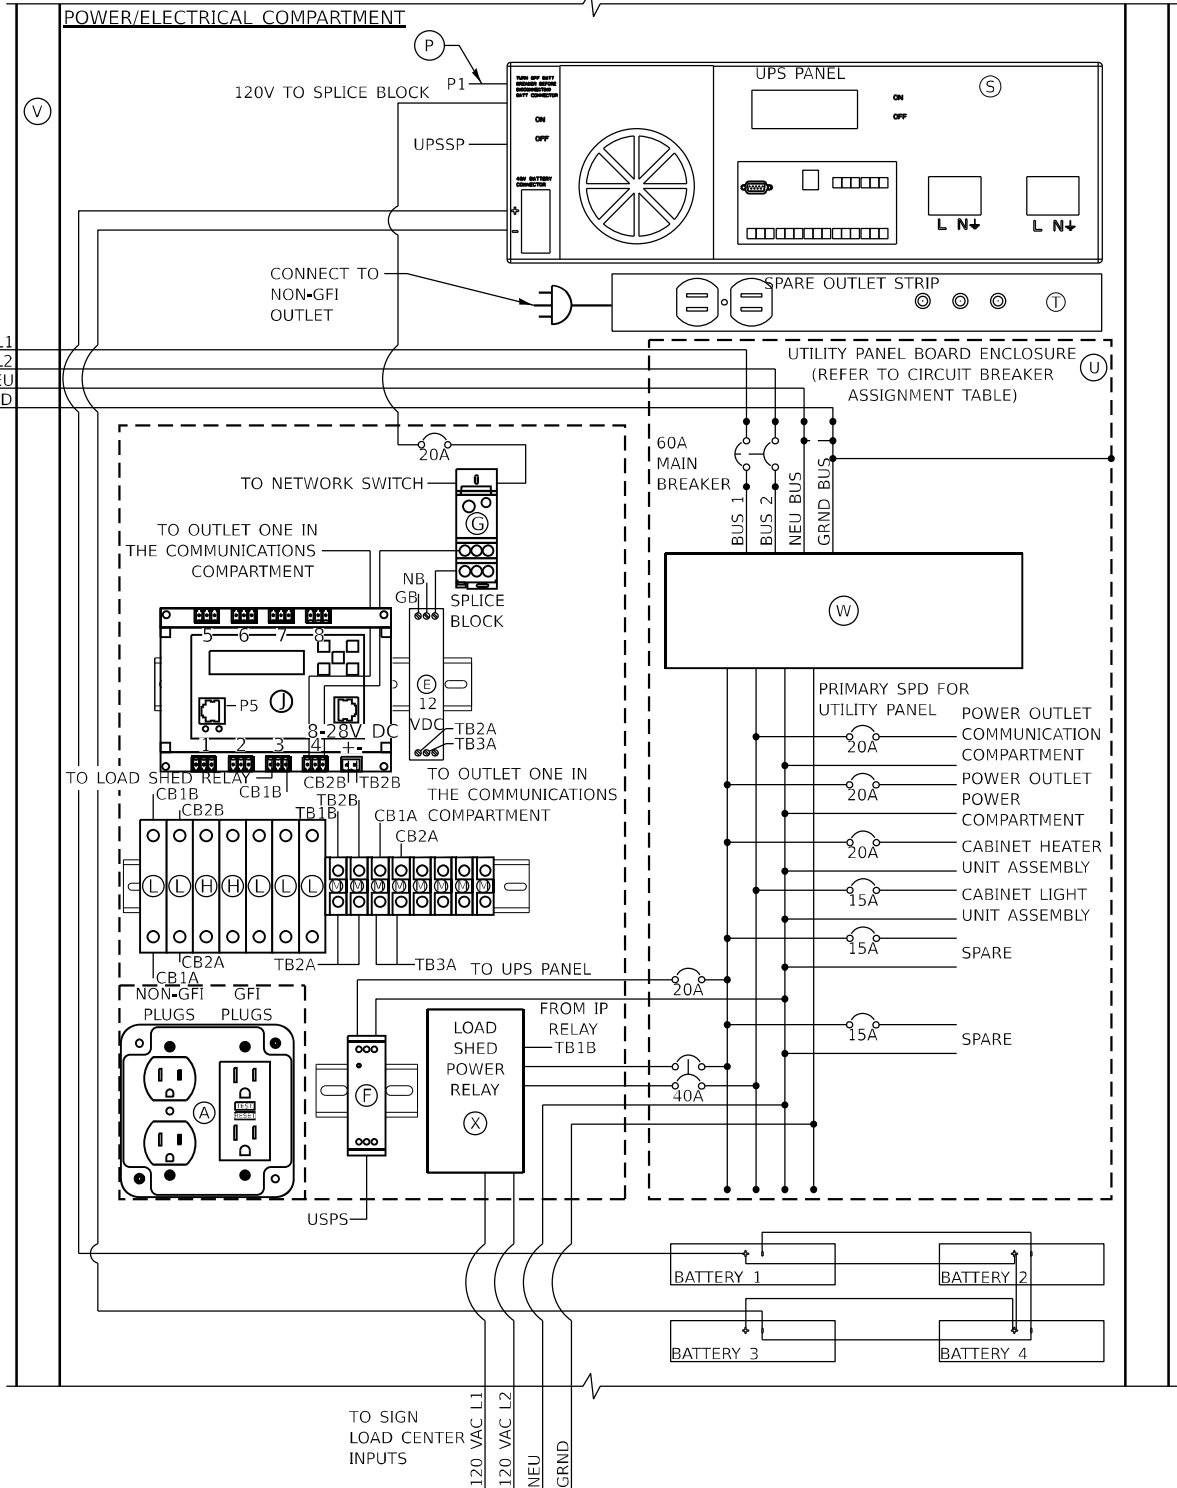

LEGEND:

| ITEM | DESCRIPTION                                                                                               |
|------|-----------------------------------------------------------------------------------------------------------|
| A    | TWO DUPLEX 120V RECEPTACLES, ONE GFCI (HUBBELL GFR5362TR) AND ONE STANDARD (HUBBELL BR20WR)               |
| B    | NETWORK SWITCH CISCO IE-4000-8T4G-E                                                                       |
| C    | NETWORK SWITCH POWER SUPPLY, PWR-IE170W-PC-AC=                                                            |
| D    | 2 METER - SMFO LC-SC DUPLEX JUMPERS, CORNING/047202R5120002M                                              |
| E    | AC/DC POWER SUPPLY, 12VDC, 10 WATTS, MEAN WELL/MDR-10-12                                                  |
| F    | 120VAC SURGE SUPPRESSOR, MOUNTED ON DIN RAIL COOPER CROUSE HINDS/MA15/D/1/SI OR APPROVED EQUAL            |
| G    | SPLICE BLOCK, ALTECH/38041                                                                                |
| H    | 5A CIRCUIT BREAKER, ALLEN BRADLEY/1492-SPM1B050                                                           |
| J    | POWER CONTROLLER, 8-CHANNEL DIN ETHERNET RELAY DIGITAL LOGGERS/DIN 4                                      |
| K    | (2) GLC-LX-SM-RGD = 1 GBPS SM SFP MODULES                                                                 |
| L    | 2A CIRCUIT BREAKER, ALLEN BRADLEY/1492-SPM1B020                                                           |
| M    | TERMINAL BLOCK, ALLEN BRADLEY/1492-CD8                                                                    |
| P    | INDOOR/OUTDOOR RATED CAT6 (1000MBS, TEMPERATURE HARDENED) THESE ARE THE CAT6 CABLES ROUTED INSIDE CABINET |
| Q    | DMS CONTROLLER                                                                                            |
| R    | 12-STRAND MULTI-MODE OR SINGLE-MODE FIBER OPTIC CABLE                                                     |
| S    | UPS PANEL ALPHA TECHNOLOGIES FXM1100 WITH BATTERIES                                                       |
| T    | OUTLET STRIP                                                                                              |
| U    | DMS MANUFACTURER UTILITY PANEL ENCLOSURE                                                                  |
| V    | DMS CONTROL CABINET TYPE 334 NEMA 4X                                                                      |
| W    | 120/240VAC MTL ZONE DEFENDER MODEL ZD16100                                                                |
| X    | LOAD SHED POWER RELAY MAGNECRAFT MODEL 199X-12 WITH COVER                                                 |
| Y    | RACK MOUNTED FIBER PATCH PANEL                                                                            |
| Z    | STAND ALONE FIBER PATCH PANEL                                                                             |
| AA   | 2 METER FIBER JUMPER, CORNING (TYPE AND CONNECTION PER DMS MANUFACTURER)                                  |


NOTES:

- FABRICATOR TO PROVIDE CABINET DRAWINGS SUBMITTAL FOR REVIEW AND APPROVAL PRIOR TO FABRICATION.
- ENTIRE COMPLETED SYSTEM SHALL BE GROUNDED AND BONDED IN ACCORDANCE WITH MOTOROLA R56 MANUAL AND THE APPLICABLE ARTICLES OF SECTION 250 OF THE NATIONAL ELECTRICAL CODE.
- DMS CONTROLLER SHOWN REPRESENTS A GENERIC DMS CONTROLLER. DMS CONTROLLERS ARE SUPPLIED BY THE DMS MANUFACTURER AND THEREFORE THE FRONT PANEL MAY DIFFER.
- REFERENCED PRODUCT MODELS MAY BE SUBSTITUTED WITH APPROVED EQUIVALENTS THAT ARE FULLY INTEROPERABLE WITH ALL DMS SYSTEM COMPONENTS.


CIRCUIT BREAKER ASSIGNMENT TABLE  
(SEE UTILITY PANEL BOARD CIRCUIT BREAKER LOCATIONS)

| CIRCUIT BREAKER DESCRIPTION            | AMPS | CIRCUIT BREAKER LOCATION |
|----------------------------------------|------|--------------------------|
| POWER OUTLET POWER COMPARTMENT         | 20   | 1                        |
| CABINET HEATER UNIT ASSEMBLY           | 20   | 2                        |
| POWER OUTLET COMMUNICATION COMPARTMENT | 20   | 3                        |
| CABINET LIGHT UNIT ASSEMBLY            | 15   | 4                        |
| LOAD SHED RELAY                        | 40   | 5                        |
| UPS PANEL                              | 20   | 6                        |
| NOT USED                               | 15   | 8                        |
| NOT USED                               | 15   | 9                        |


ITS-05

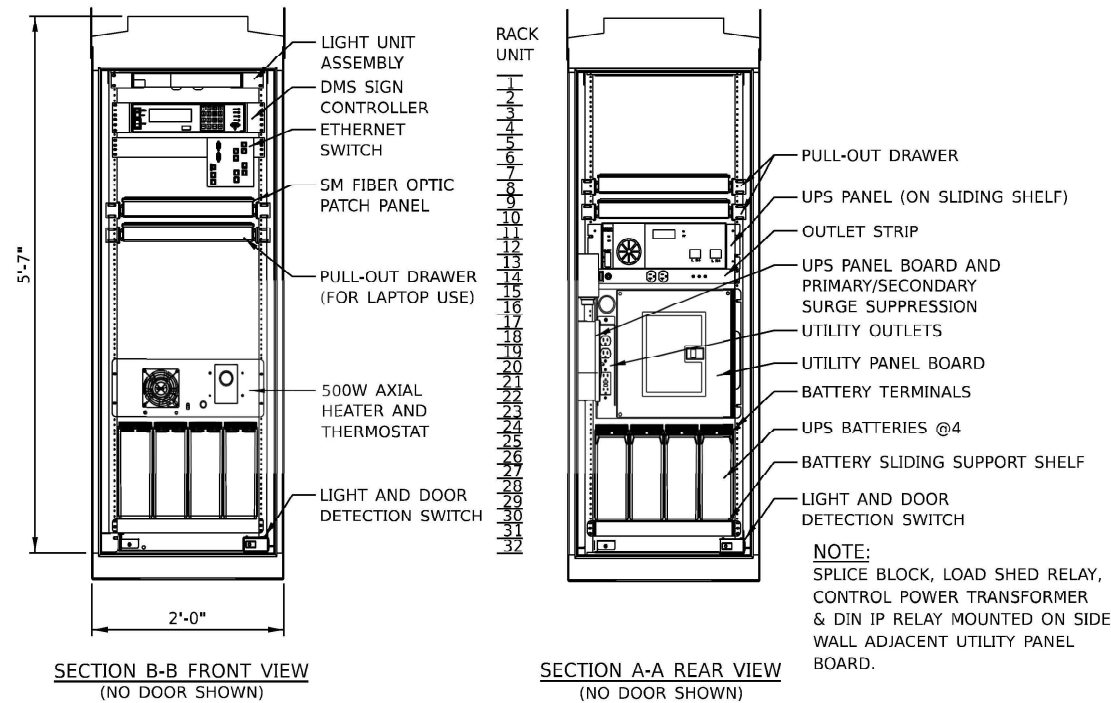

TYPE 334 DMS CABINET LAYOUT DETAILS

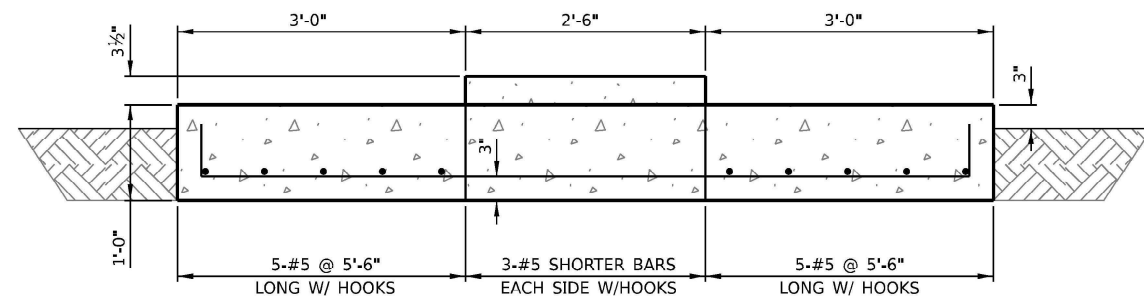

SECTION E-E

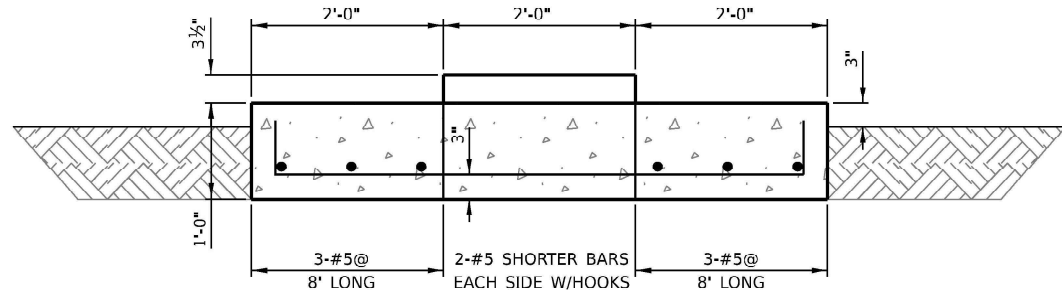


SECTION D-D  
NOT TO SCALE

DMS CONTROL CABINET FOUNDATION DETAILS

**DMS CABINET FOUNDATION NOTES:**


- COORDINATE SIZE OF OPENING WITH DMS CONTROLLER CABINET BOTTOM CONDUIT CUT-OUTS
- CONCRETE = 4,000 PSI (MIN.)
- REBAR EPOXY COATED FY=60,000 PSI (MIN.)
- PROVIDE SHOP DRAWINGS PRIOR TO CONSTRUCTION
- INCLUDE CONDUITS

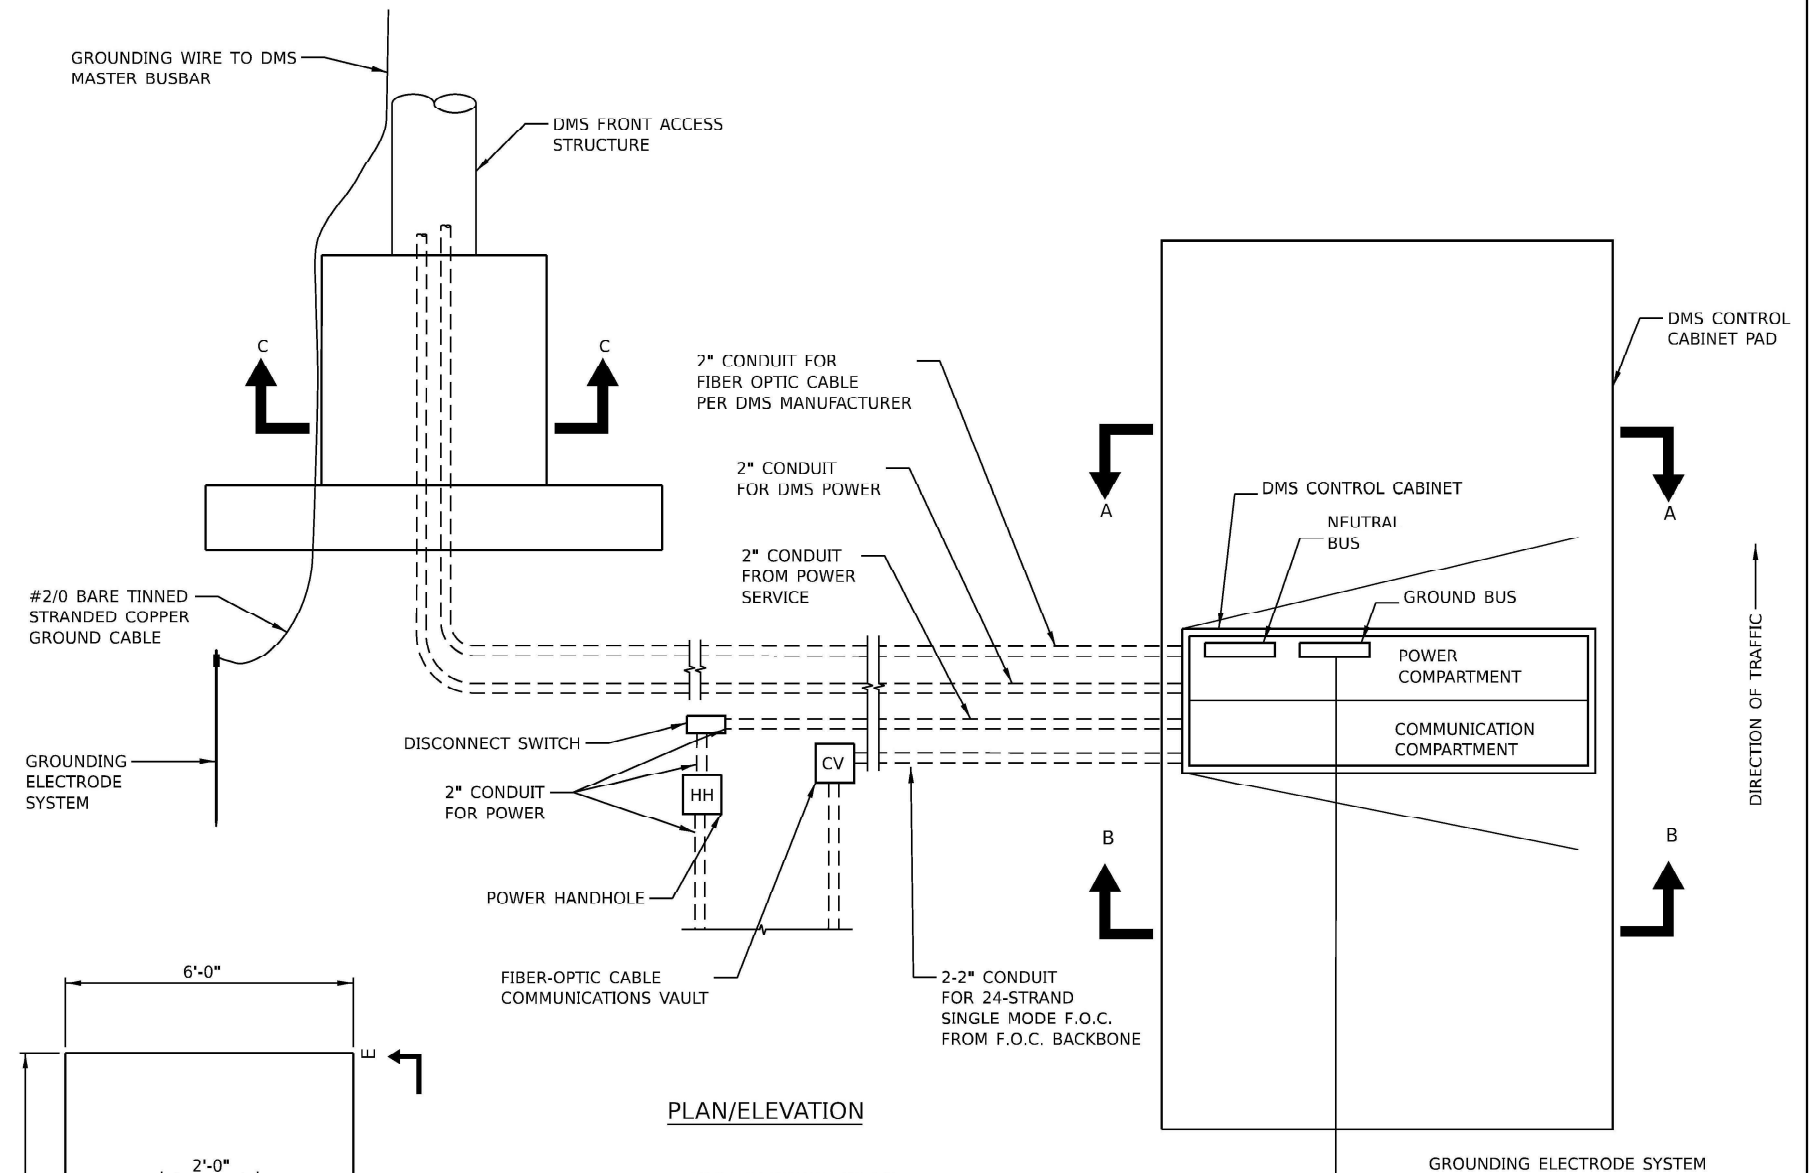

PLAN/ELEVATION

**DMS CABINET NOTES:**

- PAD MOUNT CONFIGURATION
- 0.125" ALUMINUM 5052-H34 CONSTRUCTION WITH CONTINUOUSLY WELDED EXTERNAL SEAMS
- THREE POINT LATCH WITH SST HANDLE
- DOUBLE FLANGED DOOR SEAL WITH 1#2" X 2" CLOSED CELL NEOPRENE GASKET WITH CORBIN #2 LOCK ON EACH DOOR.
- FULL LENGTH EIA GAGE FOR 19" EQUIPMENT
- ADJUSTABLE PULL OUT DRAWER
- DOOR OPENING: 21.50" X 54.75"
- FULL LENGTH STAINLESS STEEL HINGE
- ALL STAINLESS STEEL HARDWARE
- CORBIN #2 LOCK
- NEMA 4X ENCLOSURE
- SHIPPED ON WOOD PALLET
- MOUNT LAYER 2 ETHERNET SWITCH (DIN-RAIL MOUNT) USING DIN-RAIL MOUNT
- BATTERIES AND UPS SHALL BE PLACED ON A SLIDING SHELF
- CABINET DIMENSION 24"x30"x67"

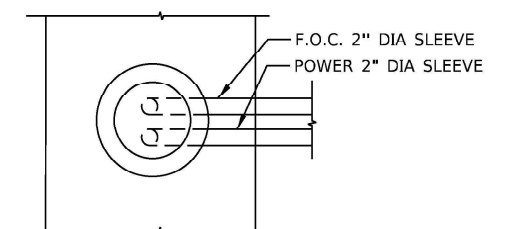

SECTION C-C  
POWER AND F.O.C. WITHIN DMS FOUNDATION

STATE OF ILLINOIS  
DEPARTMENT OF TRANSPORTATION

DMS CABINET COMMUNICATIONS FOUNDATION (2 OF 2)  
22ND ST./CERMAK RD.

SCALE: N.T.S. SHEET 1 OF SHEETS STA. TO STA.

| F.A.P. RTE.               | SECTION               | COUNTY      | TOTAL SHEETS | SHEET NO. |
|---------------------------|-----------------------|-------------|--------------|-----------|
| 365                       | 2020-265-SUR, SW & TS | DUPAGE/COOK | 492          | 345       |
| CONTRACT NO. 62N39        |                       |             |              |           |
| ILLINOIS FED. AID PROJECT |                       |             |              |           |

ITS-06

|                   |              |          |
|-------------------|--------------|----------|
| USER NAME: SUSERS | DESIGNED: YJ | REVISED: |
| DRAWN: MT         | REVISOR:     |          |
| CHECKED: ROB      | REVISOR:     |          |
| DATE: 11/22/2024  | REVISOR:     |          |

ASCERTAIN AND ASSURE CLEARANCE FROM UTILITY SECONDARY SPACE, AS APPLICABLE.

UTILITY GROUND CONNECTION, (AS APPLICABLE), BY UTILITY

UTILITY GROUND, AS APPLICABLE, (BY UTILITY)

APPROXIMATELY 10'-6" (3.2 m)

UTILITY POLE, PRIMARY CUT-OUTS TRANSFORMER(S) (AS APPLICABLE) BY THE ELECTRIC UTILITY. THE CONTRACTOR SHALL COORDINATE AS REQUIRED.

PROVIDE ADEQUATE SLACK FOR DRIP LOOP AND CONNECTION BY THE UTILITY

NON-METALLIC "U" GUARD. FURNISH FOR INSTALLATION BY ELECTRIC UTILITY. LENGTH AS REQUIRED

CONDUIT/CONDUCTOR SEALING BUSHING, SIZE AND CONDUCTOR CONFIGURATION TO MATCH SERVICE. OZ GEDNEY TYPE CSBG OR APPROVED EQUAL, COMPLETE WITH LOCKING COLLAR (SEE DETAIL)

2-HOLE STRAP FOR RIGID CONDUIT, ZINC PLATED STEEL O.Z. GEDNEY TYPE TH-1800 OR APPROVED EQUAL. ATTACHED WITH LAG SCREWS. (TYPICAL)

RIGID STEEL CONDUIT RISER (CONTINUOUS 10' (3 m) LENGTH).

HEAVY DUTY GROUND CLAMP, UNIVERSAL U-CLAMP TYPE, BY O.Z. GEDNEY, T&B OR APPROVED EQUAL.

RIGID GALVANIZED THREADED COUPLING.

PVC-COATED RIGID CONDUIT NIPPLE OR CONDUIT EXTENSION, LENGTH AS REQUIRED

PVC COATED RIGID CONDUIT ELBOW 24" (609.6 mm) RADIUS (MIN.) SEE NOTE 3.

THREADED TRANSITION COUPLING, AS APPLICABLE (SEE NOTE 6)

GROUNDING ELECTRODE CONDUCTOR, BARE COPPER, #1/0 AWG. MINIMUM

UTILITY GROUNDING ELECTRODE (AS APPLICABLE), BY UTILITY


GROUND ROD SHALL BE INSTALLED NOT LESS THAN 24" (609 mm) FROM POLE UNLESS APPROVED BY THE ENGINEER  
CUSTOMER SERVICE RISER GROUND ELECTRODE  
5/8" X 10' (15.875 mm X 3.048 m) COPPERCLAD GROUND ROD (IN UNDISTURBED SOIL) SEE NOTE 5.

APPLICATION

THIS DETAIL APPLIES FOR LOW VOLTAGE ELECTRIC SERVICE (660 V OR LESS) FROM AN OVERHEAD UTILITY SUPPLY TO SEPERATLY-MOUNTED SERVICE EQUIPMENT.

NOTES

- SERVICE VOLTAGE SHALL BE AS INDICATED ELSEWHERE IN THE DRAWINGS.
- UNLESS OTHERWISE INDICATED, ITEMS AND WORK SHALL BE INCLUDED AND PAID AS PART OF THE ELECTRIC UTILITY SERVICE INSTALLATION PAY ITEM.
- CONDUIT AND CONNECTOR DIAMETER SHALL MATCH THE DIAMETER OF THE SERVICE CONDUCTOR RACEWAY AS INDICATED ON THE PLANS.
- PVC COATED RACEWAYS AND ACCESSORIES SHALL BE CAREFULLY INSTALLED WITH MFR RECOMMENDED TOOLS AND PROCEDURES TO AVOID DAMAGE. ANY DAMAGE SHALL BE REPAIRED WITH COMPATIBLE PVC TOUCH-UP MATERIAL TO THE SATISFACTION OF THE ENGINEER OR THE DAMAGED MATERIAL SHALL BE REPLACED AT NO ADDITIONAL COST.
- THE CONTRACTOR SHALL OBTAIN INSPECTION AND APPROVAL BY THE ENGINEER OF SERVICE RISER GROUND ELECTRODE, RISER ELBOW, NIPPLE AND CONNECTION TO SERVICE CONDUCTOR RACEWAY EXTENSION BEFORE BACKFILL AND SHALL ALSO OBTAIN INSPECTION OF SERVICE RISER AND SEALING BUSHING BEFORE UTILITY "U" GUARD INSTALLATION AND SERVICE CONNECTION.
- THE HORIZONTAL ELECTRIC SERVICE CONDUCTOR RACEWAY SHALL BE AS INDICATED AND SHALL BE MEASURED SEPARATELY FOR PAYMENT. WHEN THE RACEWAY IS PVC-COATED RIGID GALVANIZED STEEL, THE COUPLING SHALL BE THE SAME. WHEN THE RACEWAY IS PVC CONDUIT (IN CONCRETE), THE COUPLING SHALL BE A METALIC TO NON METALIC ADAPTER. WHEN THE RACEWAY IS ENCASED IN CONCRETE, THE CONCRETE SHALL EXTEND TO COVER THE COUPLING.
- PLANS AND DETAILS INDICATE THE GENERAL NATURE AND REQUIREMENTS. THEY DO NOT SHOW EVERY ACCESSORY AND ATTACHMENT, AND THEY DO NOT RELIEVE THE CONTRACTOR OF THE REQUIREMENTS OF THE SPECIFICATIONS AND SPECIAL PROVISIONS TO ASCERTAIN UTILITY REQUIREMENTS AND TO COORDINATE ACCORDINGLY, FURNISHING ALL ITEMS AND WORK NOT PROVIDED BY THE UTILITY, BUT NECESSARY FOR A COMPLETE SERVICE INSTALLATION IS REQUIRED AND SHALL BE INCLUDED IN THE ELECTRIC UTILITY SERVICE INSTALLATION PAY ITEM.

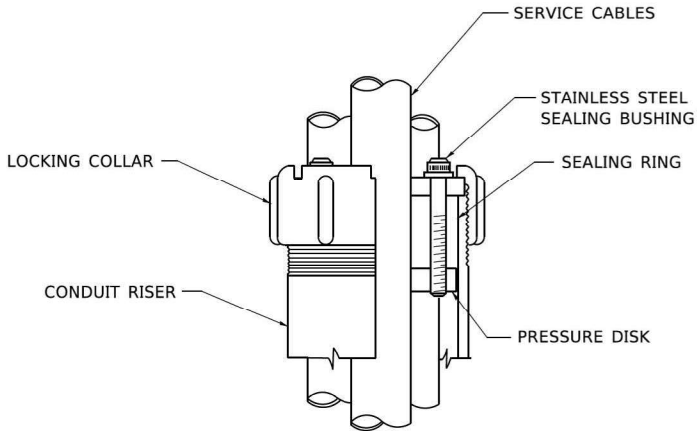

SEALING BUSHING DETAIL

ITS-07

MODEL Detail  
FILE NAME: 23884087.DOT  
5: Smart Conduit WorkCADD From AMESITS 62N339D162N394TS\_247.dgn



|                        |                   |           |
|------------------------|-------------------|-----------|
| USER NAME = \$USER\$   | DESIGNED - YJ     | REVISED - |
|                        | DRAWN - MT        | REVISED - |
| PLOT SCALE = \$SCALE\$ | CHECKED - RCB     | REVISED - |
| PLOT DATE = 11/6/2024  | DATE - 11-22-2024 | REVISED - |



STATE OF ILLINOIS  
DEPARTMENT OF TRANSPORTATION

DMS ELECTRIC SERVICE  
22ND ST./CERMAK RD.


SCALE: N.T.S. SHEET 1 OF 1 SHEETS STA. TO STA.

| F.A.P. RTE.               | SECTION               | COUNTY      | TOTAL SHEETS | SHEET NO. |
|---------------------------|-----------------------|-------------|--------------|-----------|
| 365                       | 2020-265-SUR, SW & TS | DUPAGE/COOK | 492          | 346       |
| CONTRACT NO. 62N39        |                       |             |              |           |
| ILLINOIS FED. AID PROJECT |                       |             |              |           |

MODEL Detail  
FILE NAME: 23884087.DOT 11 55 Smart Center\Work\CAADD\From AMES\ITS 62N33D162N39\ITS\_248.dgn

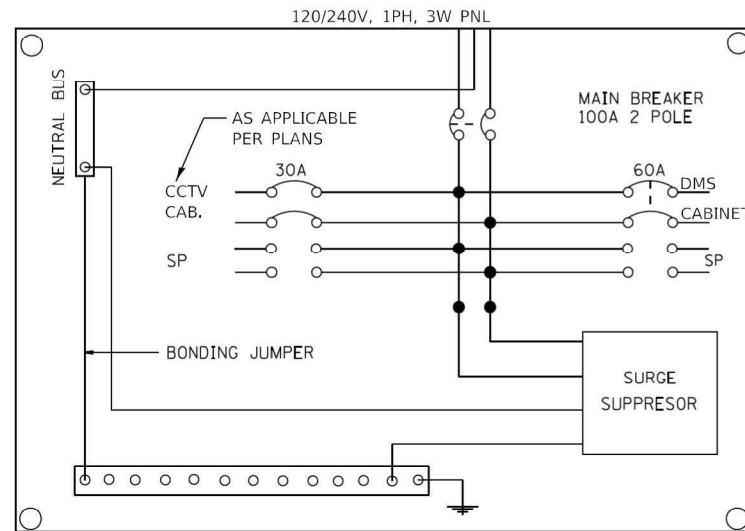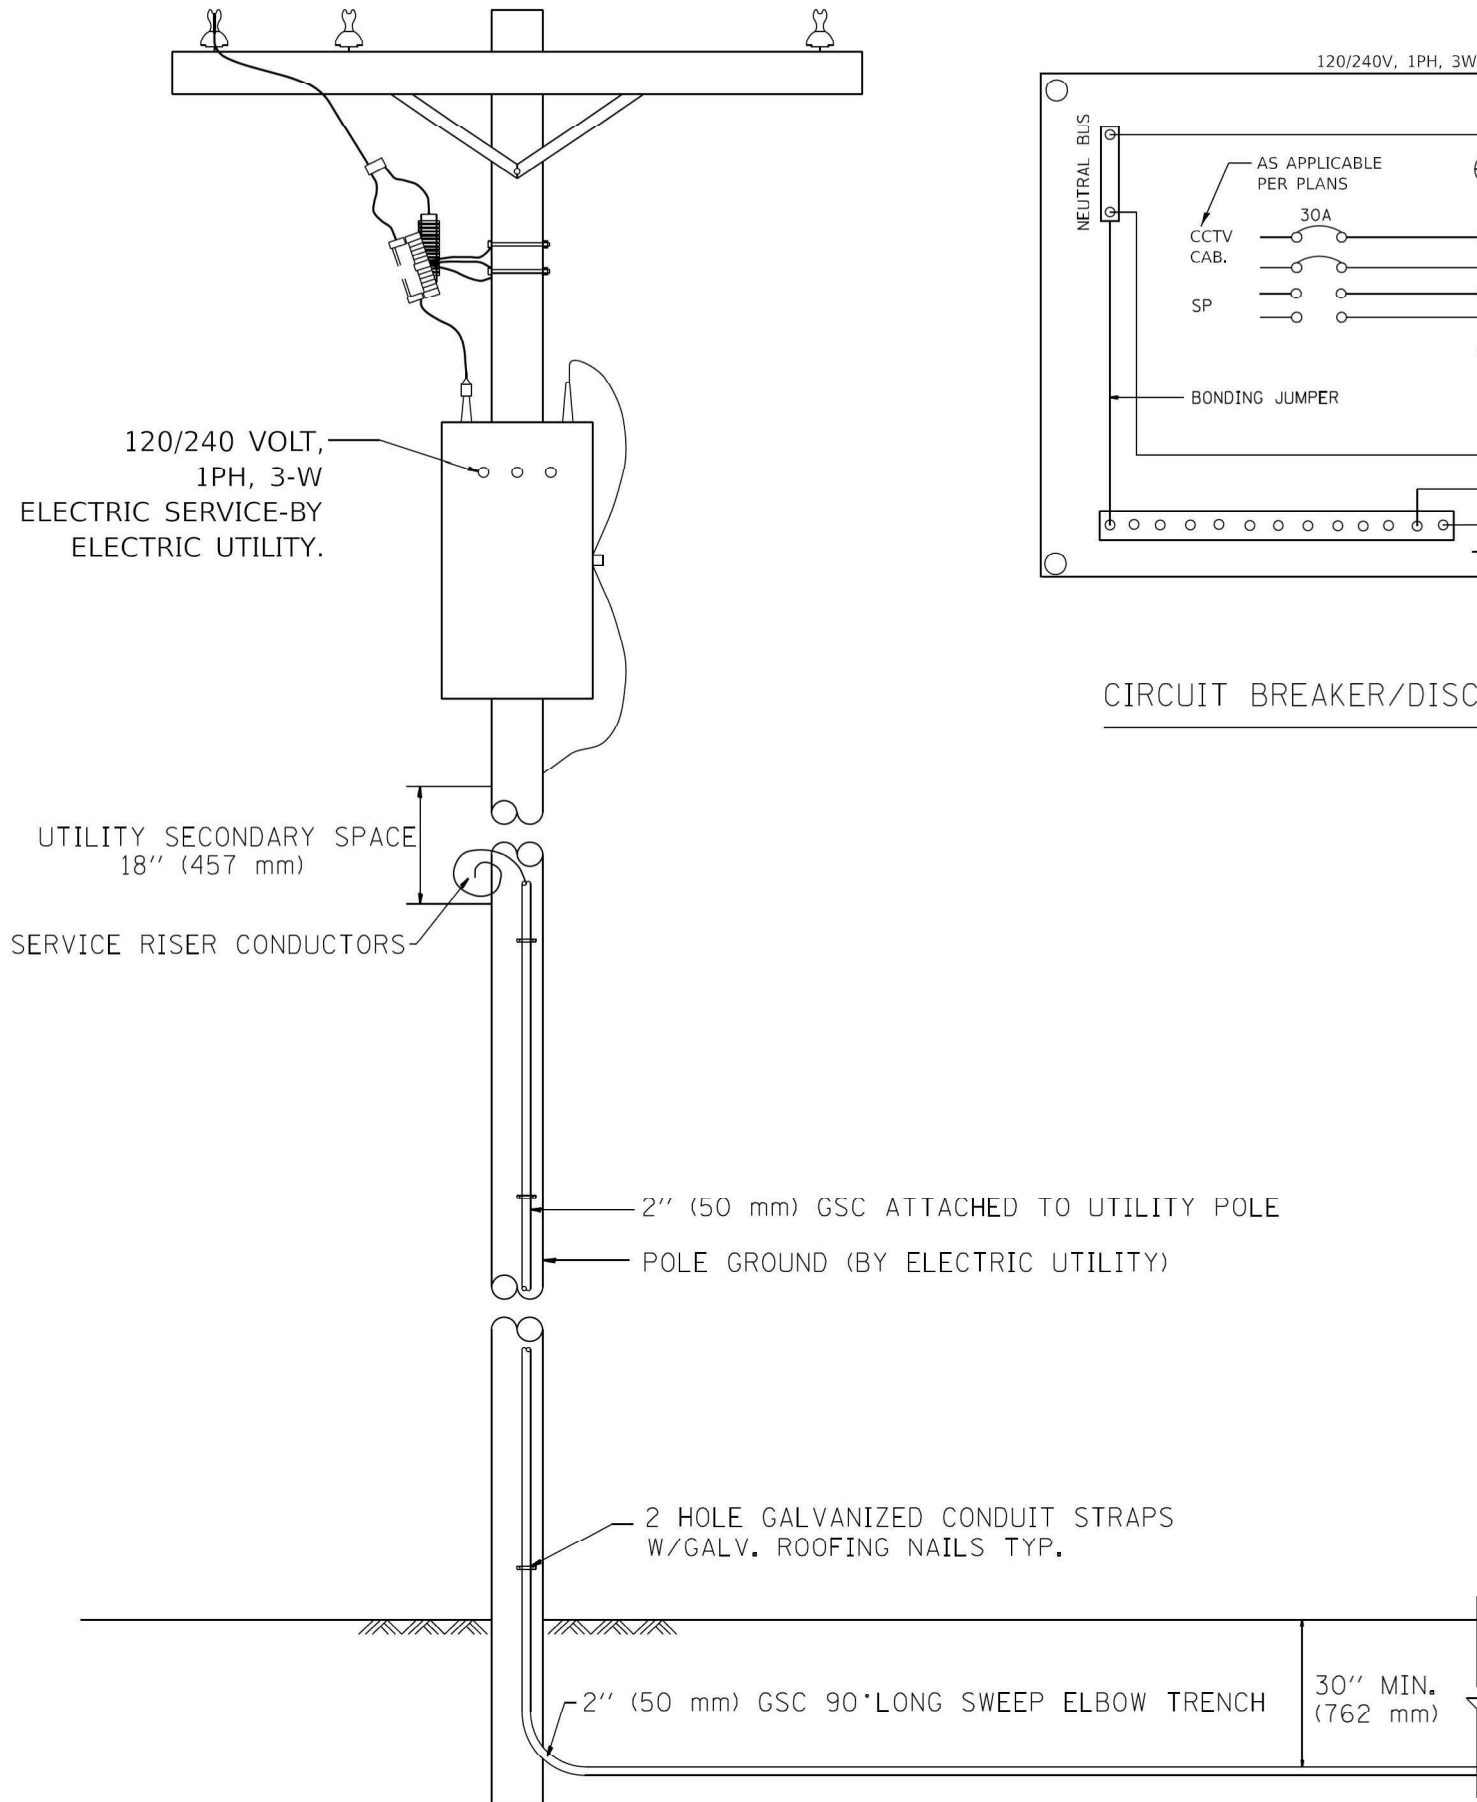

CIRCUIT BREAKER/DISCONNECT DETAIL

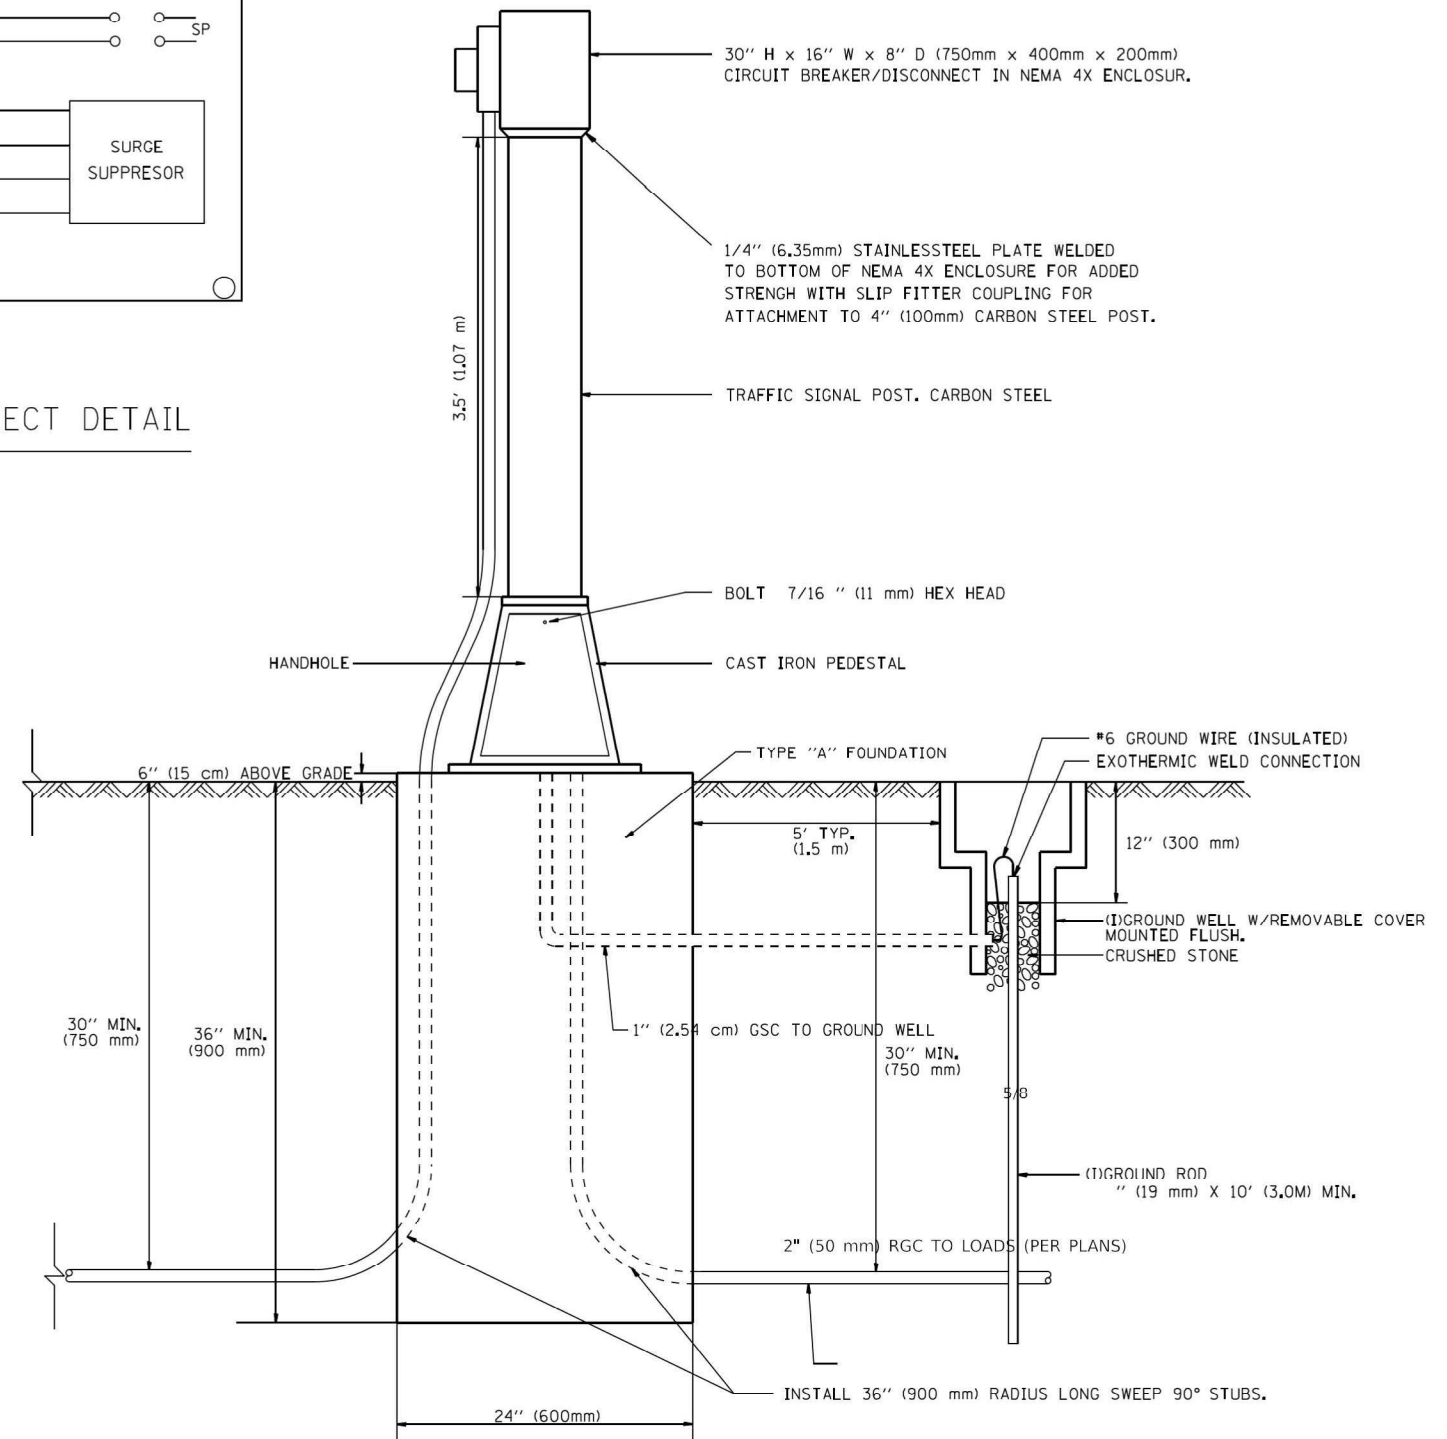

ITS-08



|                        |                   |           |
|------------------------|-------------------|-----------|
| USER NAME = \$USER\$   | DESIGNED - YJ     | REVISED - |
|                        | DRAWN - MT        | REVISED - |
| PLOT SCALE = \$SCALE\$ | CHECKED - RCB     | REVISED - |
| PLOT DATE = 11/6/2024  | DATE - 11-22-2024 | REVISED - |


STATE OF ILLINOIS  
DEPARTMENT OF TRANSPORTATION

DMS ELECTRIC METER  
22ND ST./CERMAK RD.


SCALE: N.T.S. SHEET 1 OF 1 SHEETS STA. TO STA.

| F.A.P.<br>RTE.            | SECTION               | COUNTY      | TOTAL<br>SHEETS | SHEET<br>NO. |
|---------------------------|-----------------------|-------------|-----------------|--------------|
| 365                       | 2020-265-SUR, SW & TS | DUPAGE/COOK | 492             | 347          |
| CONTRACT NO. 62N39        |                       |             |                 |              |
| ILLINOIS FED. AID PROJECT |                       |             |                 |              |




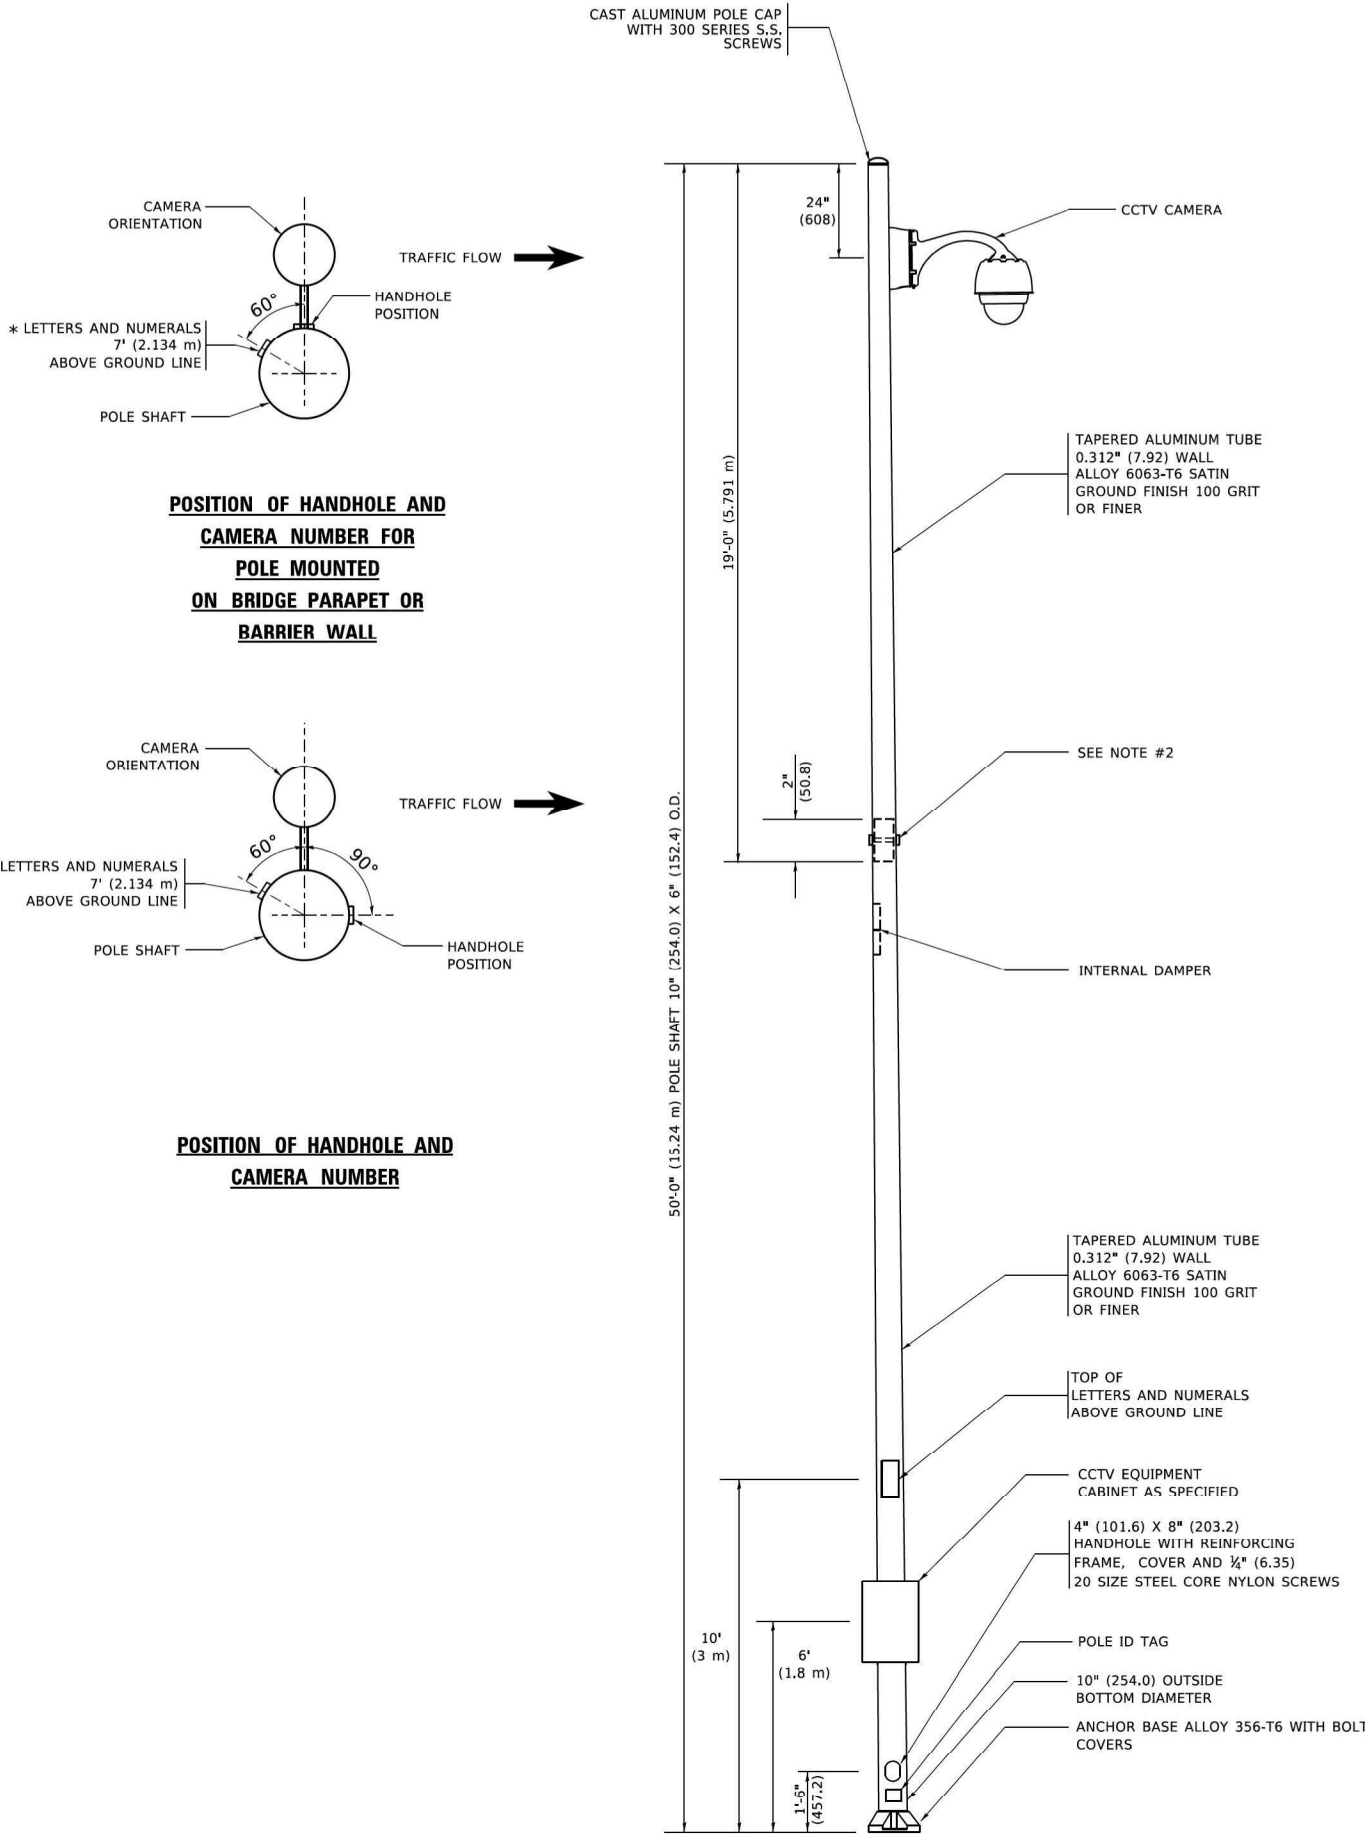

- NOTES:
1. ALL DIMENSIONS ARE IN INCHES (MILLIMETERS) UNLESS OTHERWISE SHOWN.
  2. TWO PIECE SHAFT WILL BE MATCHED MARKED AND INTERCHANGEABLE BETWEEN DIFFERENT UNITS. FIELD DRILLING OF THE HOLES WILL NOT BE ALLOWED.
  3. THE POLE WILL MEET AASHTO DESIGN CRITERIA AS SPECIFIED.
  4. THE INSTALLING CONTRACTOR WILL PROVIDE A UL LISTED GROUNDING CONNECTOR. BURNDY K2C23, T&B SP4DL OR APPROVED EQUAL.
  5. POLES WILL BE INSTALLED IN ACCORDANCE TO MANUFACTURER'S INSTRUCTIONS.
  6. POLES WILL BE SET PLUMB ON THE FOUNDATION WITHOUT THE USE OF LEVELING NUTS, WASHERS OR SHIMS.

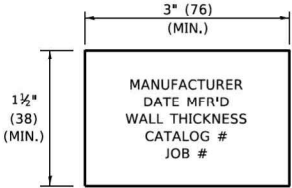


POLE ID TAG  
NTS

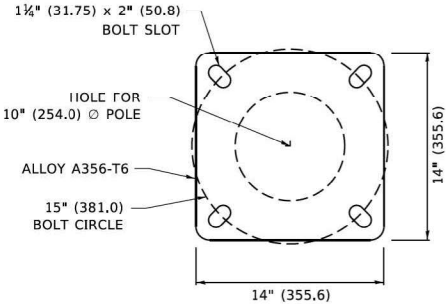

POLE BASE PLATE DETAIL

15 INCH (381.0) BOLT CIRCLE

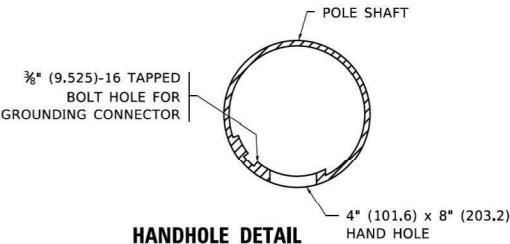

HANDHOLE DETAIL  
(N.T.S.)

ITS-09

MODEL: D:\data\23884087.DOT\11-55 Smart Corridor\Work\CADD\From Ames\ITS 62N33D162N39\ITS\_249.dgn  
FILE NAME: 23884087.DOT\11-55 Smart Corridor\Work\CADD\From Ames\ITS 62N33D162N39\ITS\_249.dgn



|            |               |
|------------|---------------|
| USER NAME  | = \$USERS     |
| PLOT SCALE | = \$\$SCALE\$ |
| PLOT DATE  | = 11/6/2024   |

|            |            |
|------------|------------|
| DESIGNED - | YJ         |
| DRAWN -    | MT         |
| CHECKED -  | RCB        |
| DATE -     | 11-22-2024 |

|           |  |
|-----------|--|
| REVISED - |  |
| REVISED - |  |
| REVISED - |  |
| REVISED - |  |

STATE OF ILLINOIS  
DEPARTMENT OF TRANSPORTATION

CCTV CAMERA POLE  
22ND ST./CERMAK RD.

SCALE: 1"=20' SHEET 1 OF 1 SHEETS STA. TO STA.

| F.A.P. RTE.               | SECTION               | COUNTY      | TOTAL SHEETS | SHEET NO. |
|---------------------------|-----------------------|-------------|--------------|-----------|
| 365                       | 2020-265-SUR, SW & TS | DUPAGE/COOK | 492          | 348       |
| CONTRACT NO. 62N39        |                       |             |              |           |
| ILLINOIS FED. AID PROJECT |                       |             |              |           |



| SOIL CONDITIONS                     | DESIGN DEPTH "D" OF FOUNDATION |
|-------------------------------------|--------------------------------|
| SOFT CLAY<br>Qu = 0.375 TON/SQ. FT. | 13'-0" (3.96 m)                |
| MEDIUM CLAY<br>Qu = 0.75 TON/SQ.FT  | 9'-6" (2.09 m)                 |
| STIFF CLAY<br>Qu = 1.50 TON/SQ. FT. | 7'-0" (2.13 m)                 |
| LOOSE SAND<br>ϕ = 34°               | 9'-0" (2.74 m)                 |
| MEDIUM SAND<br>ϕ = 37.5°            | 8'-3" (2.52 m)                 |
| DENSE SAND<br>ϕ = 40°               | 7'-9" (2.36 m)                 |



1. ALL DIMENSIONS ARE IN INCHES (MILLIMETERS) UNLESS OTHERWISE SHOWN.
2. THE ANCHOR RODS AND RACEWAYS SHALL BE PROPERLY SECURED IN PLACE BEFORE THE CONCRETE IS PLACED.
3. THE FOUNDATION SHALL NOT PROTRUDE MORE THAN 100MM (4 IN.) ABOVE THE FINISHED GRADE WITHIN A 60 IN. (1.5 m) CHORD ACROSS THE FOUNDATION, WITH ANCHOR RODS INCLUDED, IN ACCORDANCE WITH AASHTO GUIDELINES. IF THE FOUNDATION HEIGHT, INCLUDING ANCHOR RODS, EXTENDS BEYOND THESE SPECIFIED LIMITS, THE FOUNDATION SHALL BE REPLACED AT THE CONTRACTOR'S EXPENSE. SEE FOUNDATION EXTENSION DETAIL.
4. THE HOLE FOR THE FOUNDATION SHALL BE MADE BY DRILLING WITH AN AUGER, OF THE SAME DIAMETER AS THE FOUNDATION. IF SOIL CONDITIONS REQUIRE THE USE OF A LINER TO FORM THE HOLE, THE LINER SHALL BE WITHDRAWN AS THE CONCRETE IS DEPOSITED.
5. THE TOP OF THE FOUNDATION SHALL BE CONSTRUCTED LEVEL. A LINER OR FORM SHALL BE USED TO PRODUCE A UNIFORM SMOOTH SIDE TO THE TOP OF THE FOUNDATION. FOUNDATION TOP SHALL BE CHAMFERED  $\frac{3}{4}$ -IN. (20 mm).
6. THE CONCRETE SHALL BE CLASS SI. CONCRETE SHALL CURE ACCORDING TO ARTICLE 1020.13 BEFORE LIGHT POLES ARE INSTALLED.
7. THE ANCHOR ROD SHALL BE A HOOK ROD TYPE. COLD BENDING OF THE ANCHOR ROD WILL NOT BE ALLOWED. THE RADIUS OF THE HOOK BEND SHALL NOT BE LESS THAN 4 TIMES THE NOMINAL DIAMETER OF THE ANCHOR ROD. A TACK WELDED ANCHOR ROD MAY BE SUBSTITUTED WITH THE APPROVAL OF THE ENGINEER.
8. THE ANCHOR RODS SHALL BE ACCORDING TO ASTM F1554 GRADE 725 (GRADE 105). NUTS SHALL BE HEXAGON NUTS ACCORDING TO ASTM A 194 2H OR ASTM A 563 DH, AND WASHERS SHALL BE ACCORDING TO ASTM F 436.
9. ANCHOR RODS, NUTS AND WASHERS SHALL BE COMPLETELY GALVANIZED BY EITHER THE HOT-DIPPED PROCESS CONFORMING WITH AASHTO M 232, THE MECHANICAL PLATING METHOD CONFORMING TO AASHTO M 298, CLASS 50 WITH A MAXIMUM COATING THICKNESS OF 150 UM(6 MILS) OR THE ELECTROLYTIC PROCESS ACCORDING TO ASTM F 1136.
10. THE ANCHOR RODS SHALL BE THREADED A MINIMUM OF 6 INCHES (150 mm) WITH A MINIMUM OF 3 INCHES (75 mm) OF THREADED ANCHOR ROD EMBEDDED IN THE FOUNDATION.
11. ANCHOR RODS SHALL PROJECT  $2\frac{3}{4}$ " (69.9 mm) ABOVE THE TOP OF THE FOUNDATION. IF BREAKAWAY COUPLINGS ARE SPECIFIED, THE CONTRACTOR SHALL CAREFULLY COORDINATE THE ANCHOR ROD PROJECTION WITH THE INSTALLATION REQUIREMENTS OF THE BREAKAWAY COUPLINGS.
12. THE CONTRACTOR SHALL USE A #3 SPIRAL AT 6" (152.4 mm) PITCH OR MAY SUBSTITUTE #3 TIES AT 12" (304.8 mm) O.C. WITH THE APPROVAL OF THE ENGINEER.
13. THE CABLE TRENCHES AND FOUNDATION SHALL BE BACK FILLED AND COMPACTED AS SPECIFIED BEFORE THE LIGHT POLE IS ERECTED.
14. THE RACEWAYS SHALL PROJECT 1" (25.4 mm) ABOVE THE TOP OF THE FOUNDATION.
15. ANCHOR ROD BOLT CIRCLE TO BE COORDINATED WITH CAMERA STRUCTURE



|                        |                   |           |
|------------------------|-------------------|-----------|
| USER NAME = \$USER\$   | DESIGNED - YJ     | REVISED - |
|                        | DRAWN - MT        | REVISED - |
| PLOT SCALE = \$SCALE\$ | CHECKED - RCB     | REVISED - |
| PLOT DATE = 11/6/2024  | DATE - 11-22-2024 | REVISED - |


STATE OF ILLINOIS  
DEPARTMENT OF TRANSPORTATION

**CCTV CAMERA POLE FOUNDATION**  
**22ND ST./CERMAK RD.**


|               |         |      |        |      |         |
|---------------|---------|------|--------|------|---------|
| SCALE: 1"=20' | SHEET 1 | OF 1 | SHEETS | STA. | TO STA. |
|---------------|---------|------|--------|------|---------|

|                    |                       |                  |                 |              |
|--------------------|-----------------------|------------------|-----------------|--------------|
| F.A.P.<br>RTE.     | SECTION               | COUNTY           | TOTAL<br>SHEETS | SHEET<br>NO. |
| 365                | 2020-265-SUR, SW & TS | DUPAGE/COOK      | 492             | 349          |
| CONTRACT NO. 62N39 |                       |                  |                 |              |
| ILLINOIS           |                       | FED. AID PROJECT |                 |              |




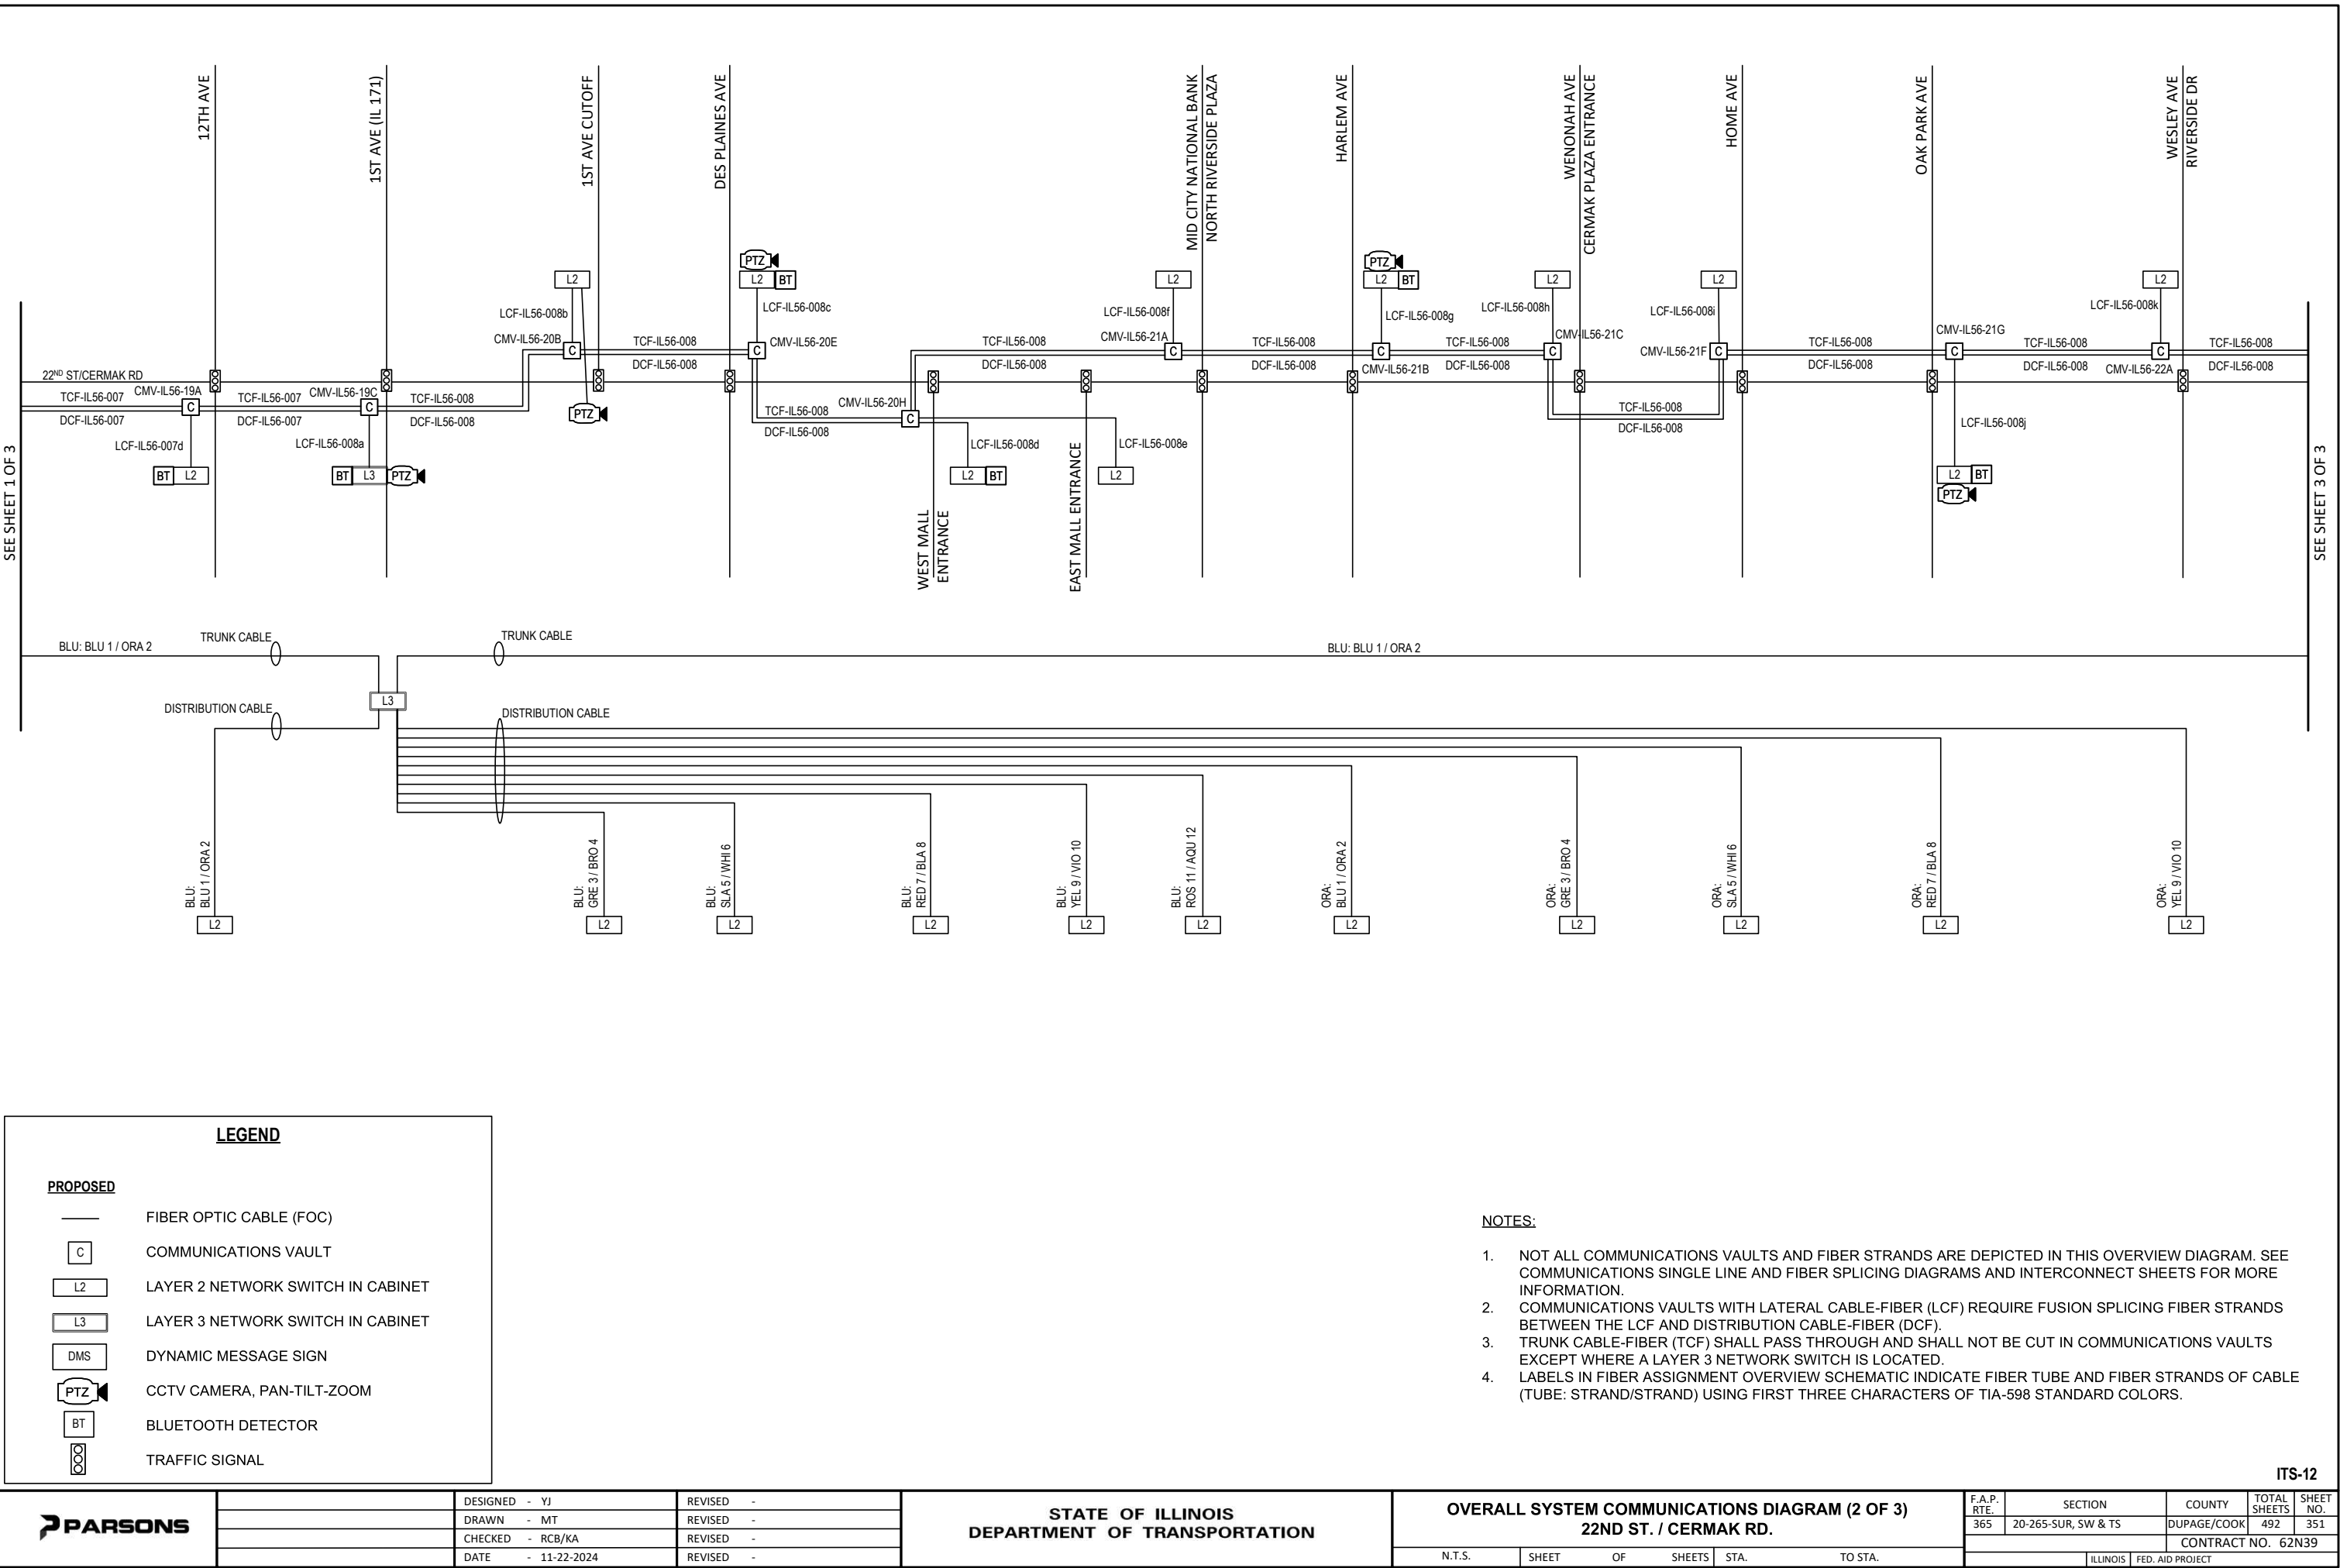

SEE SHEET 2 OF 3

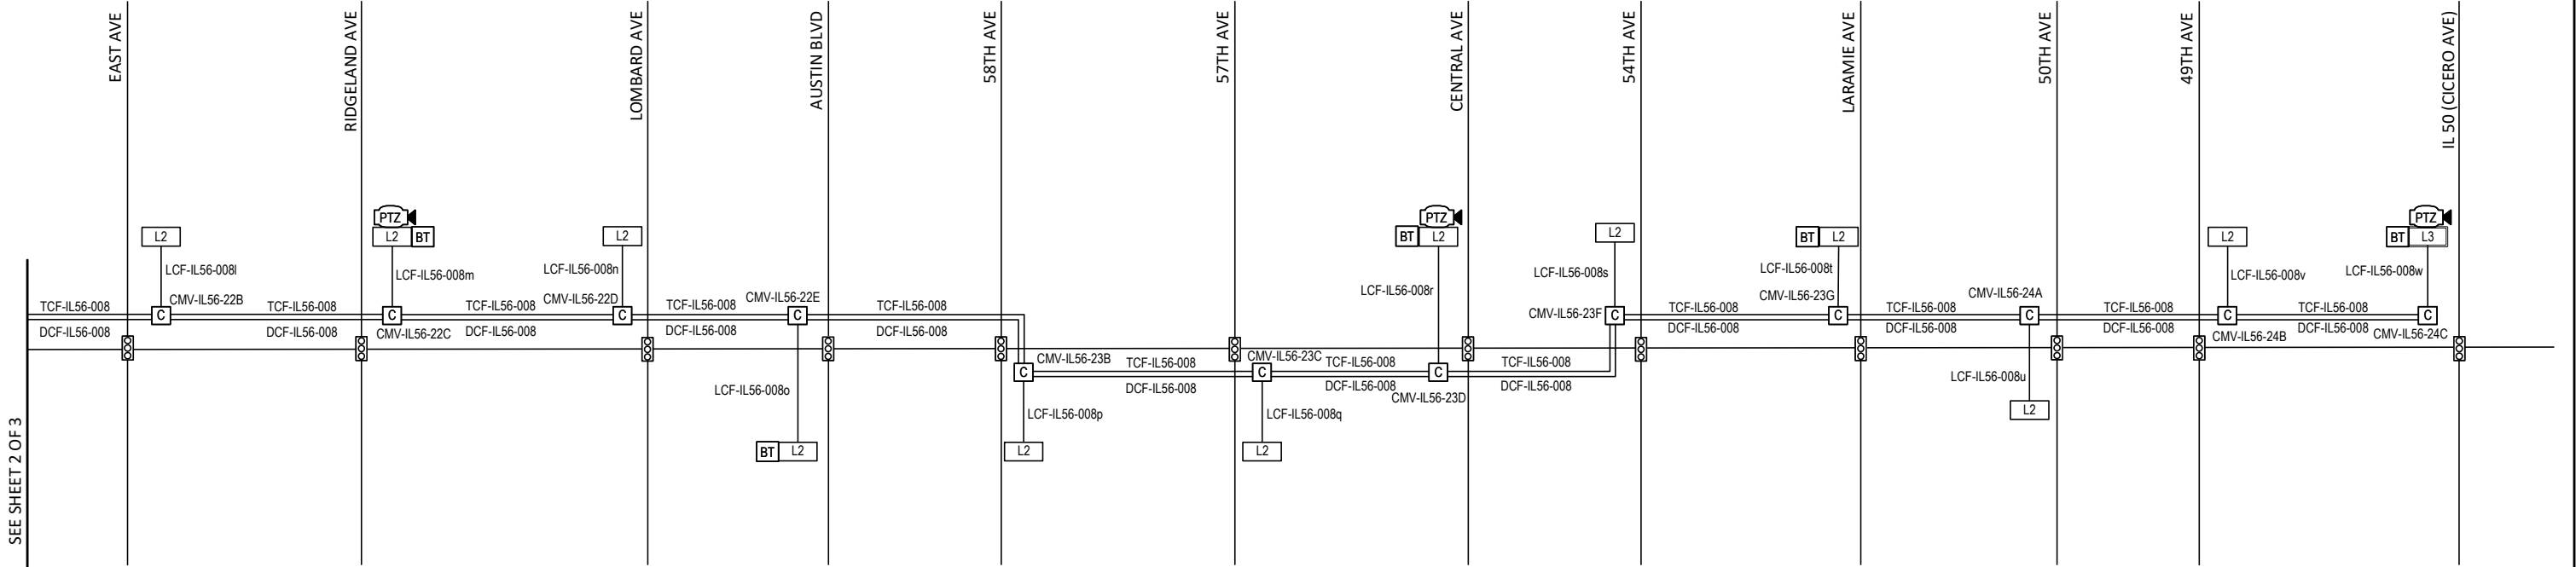

BLU: BLU 1 / ORA 2

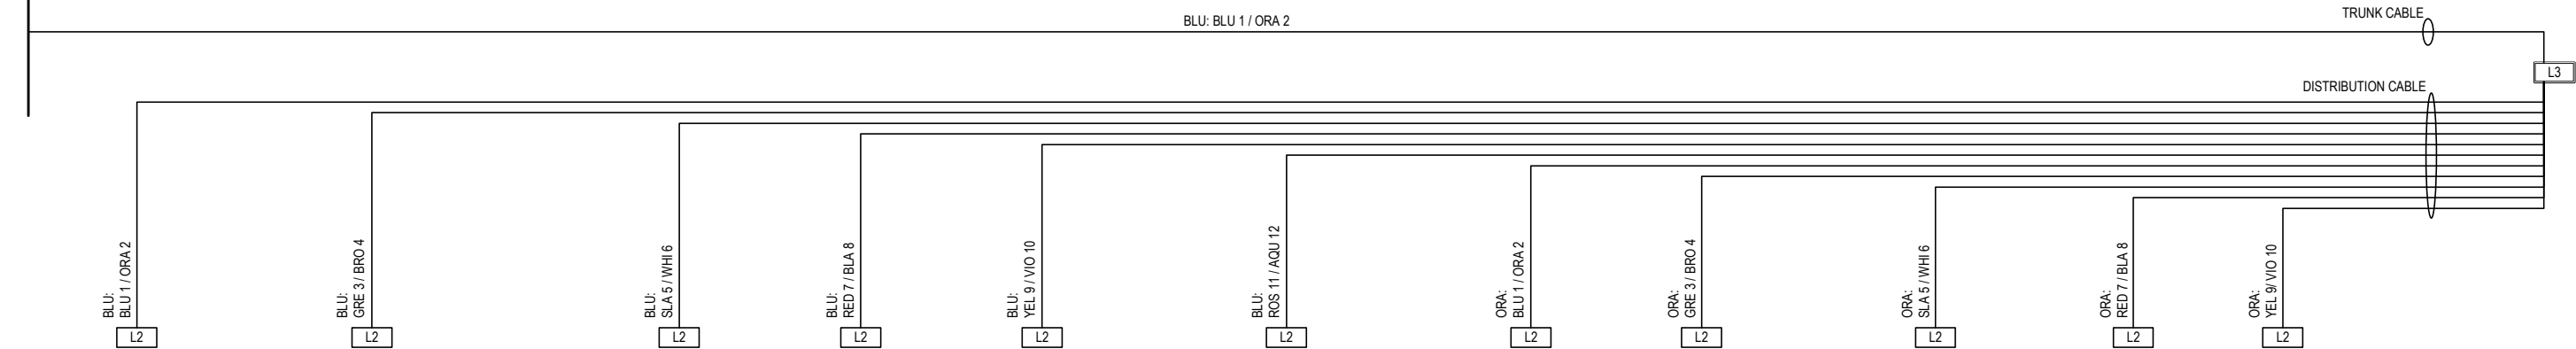

### LEGEND

#### PROPOSED

- FIBER OPTIC CABLE (FOC)
- COMMUNICATIONS VAULT
- LAYER 2 NETWORK SWITCH IN CABINET
- LAYER 3 NETWORK SWITCH IN CABINET
- DYNAMIC MESSAGE SIGN
- CCTV CAMERA, PAN-TILT-ZOOM
- BLUETOOTH DETECTOR
- TRAFFIC SIGNAL

#### NOTES:

- NOT ALL COMMUNICATIONS VAULTS AND FIBER STRANDS ARE DEPICTED IN THIS OVERVIEW DIAGRAM. SEE COMMUNICATIONS SINGLE LINE AND FIBER SPLICING DIAGRAMS AND INTERCONNECT SHEETS FOR MORE INFORMATION.
- COMMUNICATIONS VAULTS WITH LATERAL CABLE-FIBER (LCF) REQUIRE FUSION SPLICING FIBER STRANDS BETWEEN THE LCF AND DISTRIBUTION CABLE-FIBER (DCF).
- TRUNK CABLE-FIBER (TCF) SHALL PASS THROUGH AND SHALL NOT BE CUT IN COMMUNICATIONS VAULTS EXCEPT WHERE A LAYER 3 NETWORK SWITCH IS LOCATED.
- LABELS IN FIBER ASSIGNMENT OVERVIEW SCHEMATIC INDICATE FIBER TUBE AND FIBER STRANDS OF CABLE (TUBE: STRAND/STRAND) USING FIRST THREE CHARACTERS OF TIA-598 STANDARD COLORS.



DESIGNED - YJ  
DRAWN - MT  
CHECKED - RCB/KA  
DATE - 11-22-2024

REVISED -  
REVISED -  
REVISED -  
REVISED -


STATE OF ILLINOIS  
DEPARTMENT OF TRANSPORTATION



OVERALL SYSTEM COMMUNICATIONS DIAGRAM (3 OF 3)  
22ND ST. / CERMAK RD.

N.T.S. SHEET OF SHEETS STA. TO STA.


| F.A.P. RTE.               | SECTION             | COUNTY      | TOTAL SHEETS | SHEET NO. |
|---------------------------|---------------------|-------------|--------------|-----------|
| 365                       | 20-265-SUR, SW & TS | DUPAGE/COOK | 492          | 352       |
| CONTRACT NO. 62N39        |                     |             |              |           |
| ILLINOIS FED. AID PROJECT |                     |             |              |           |

ITS-13

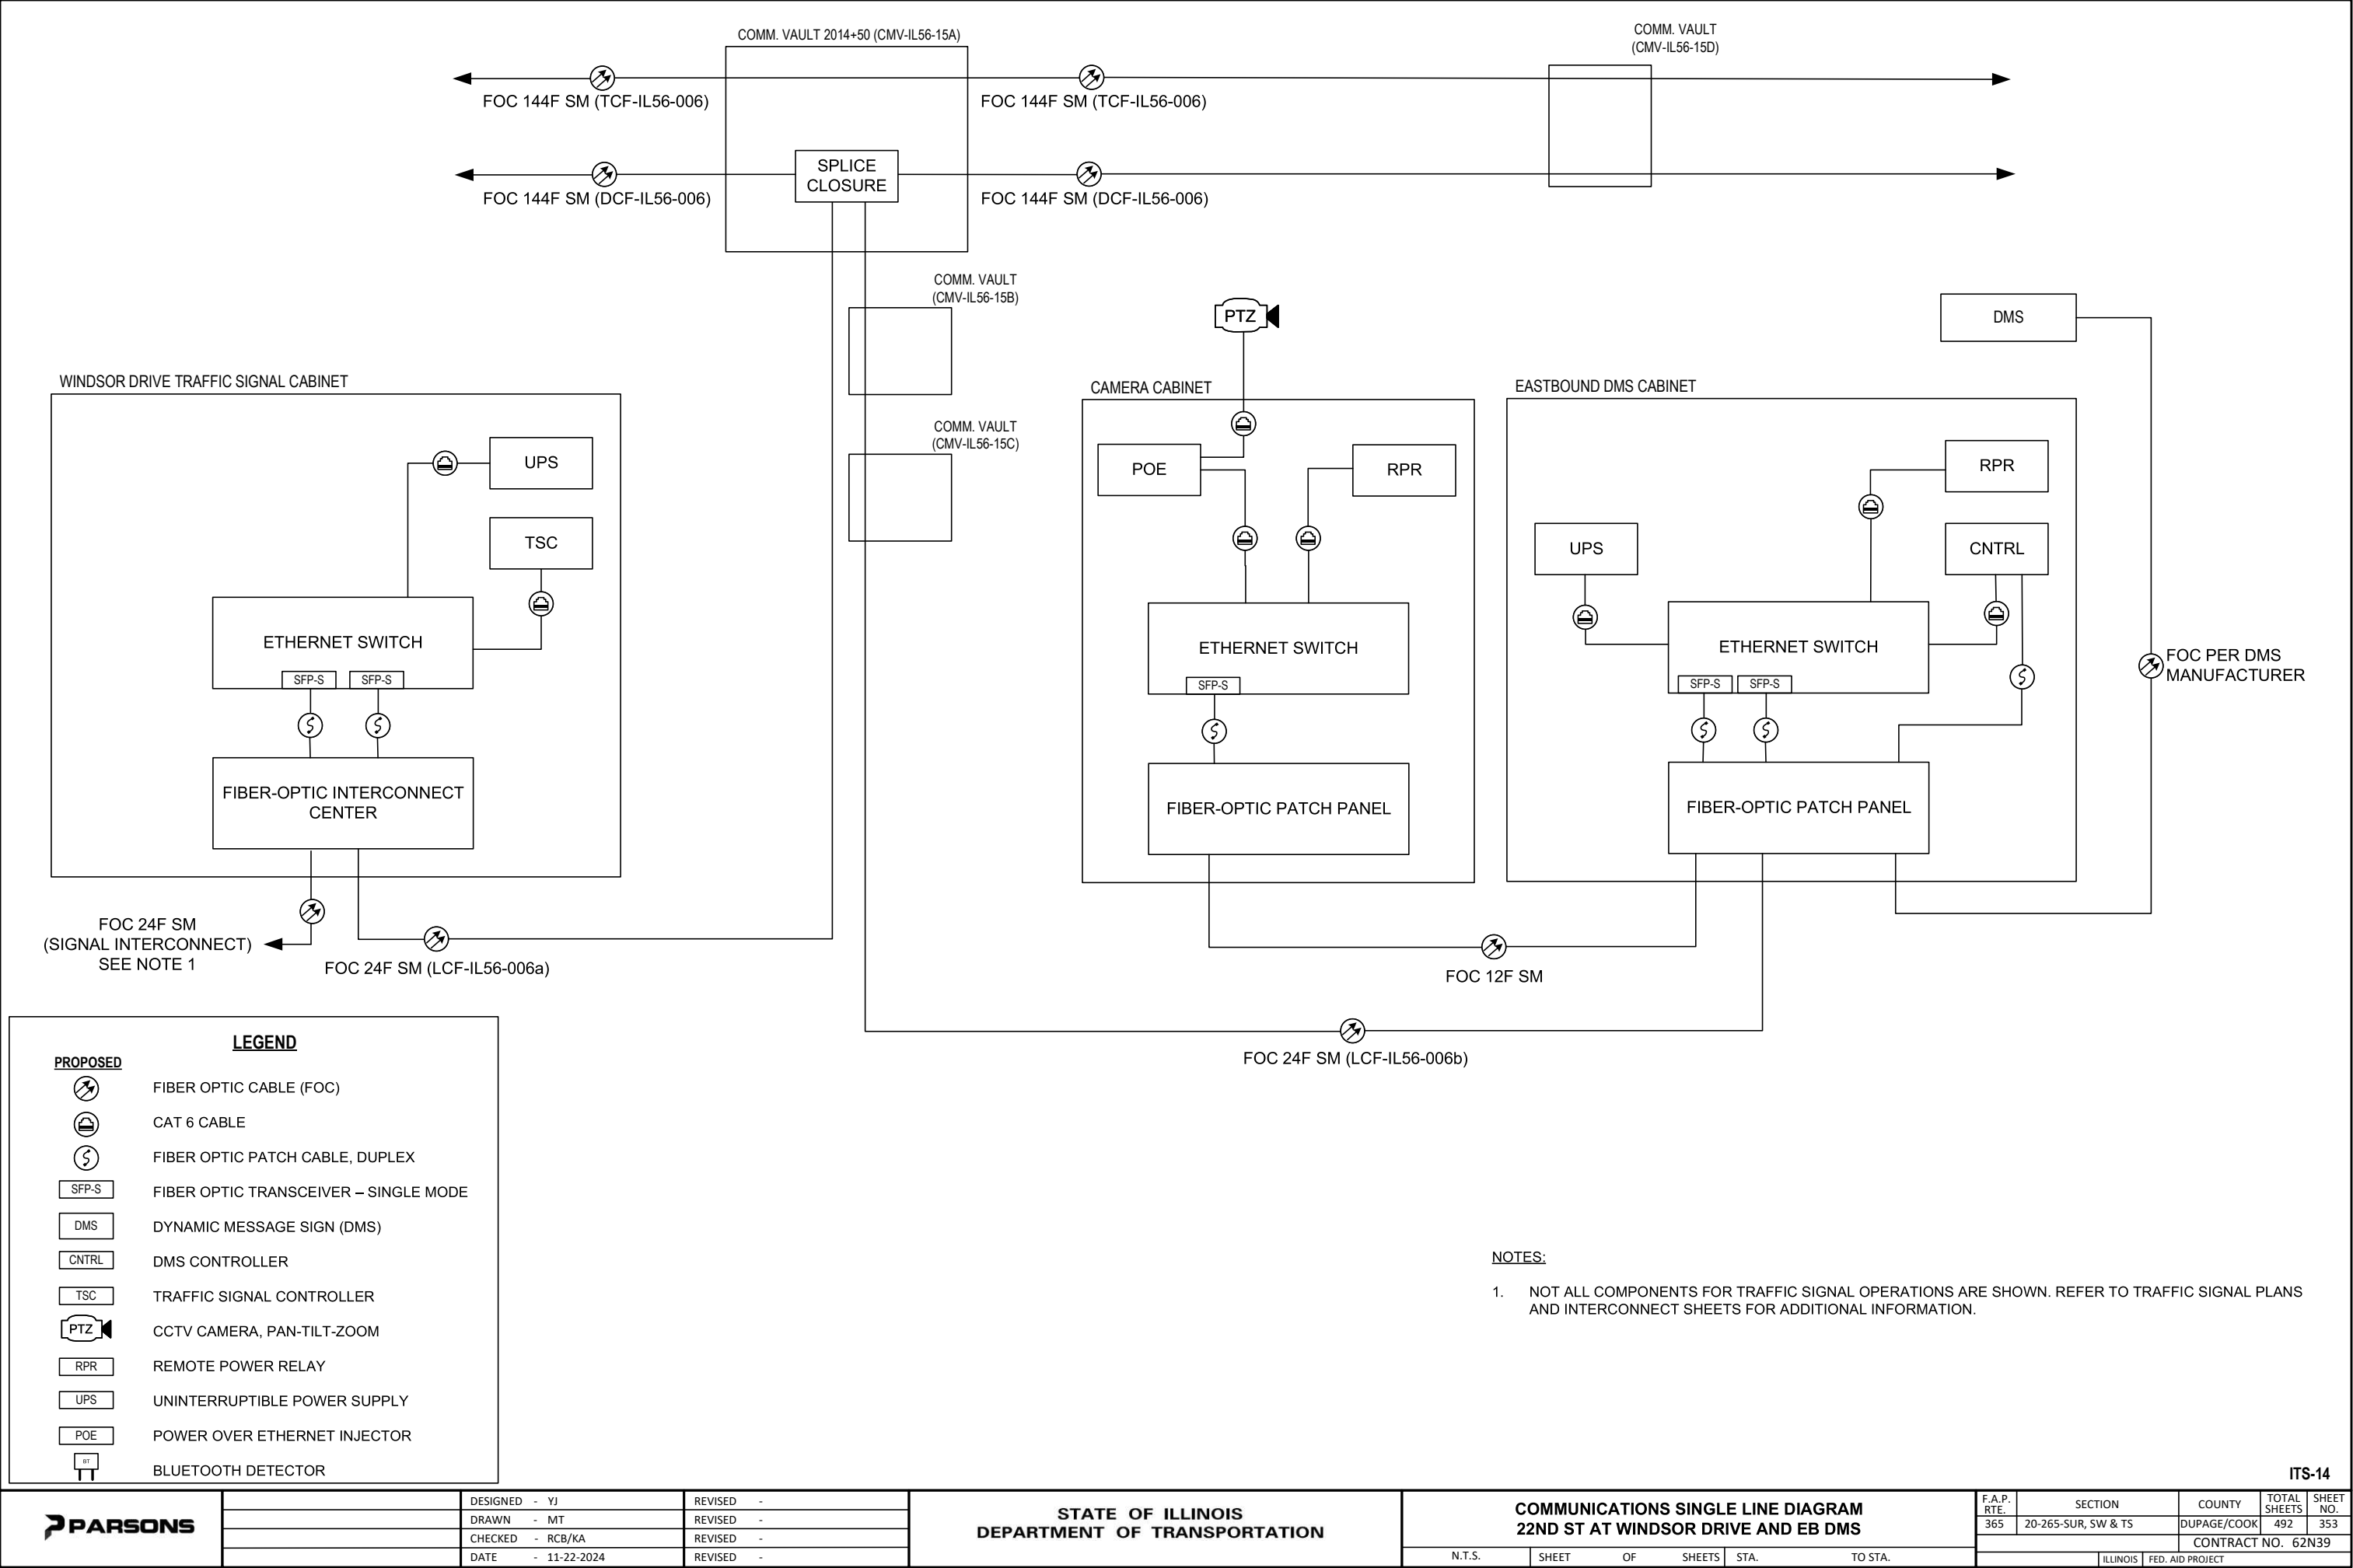


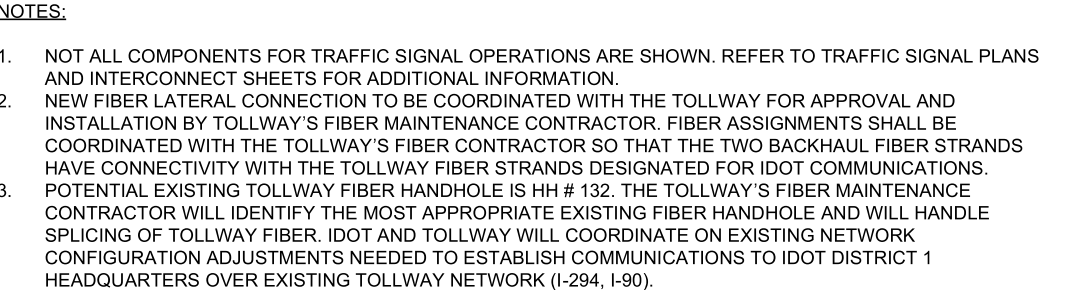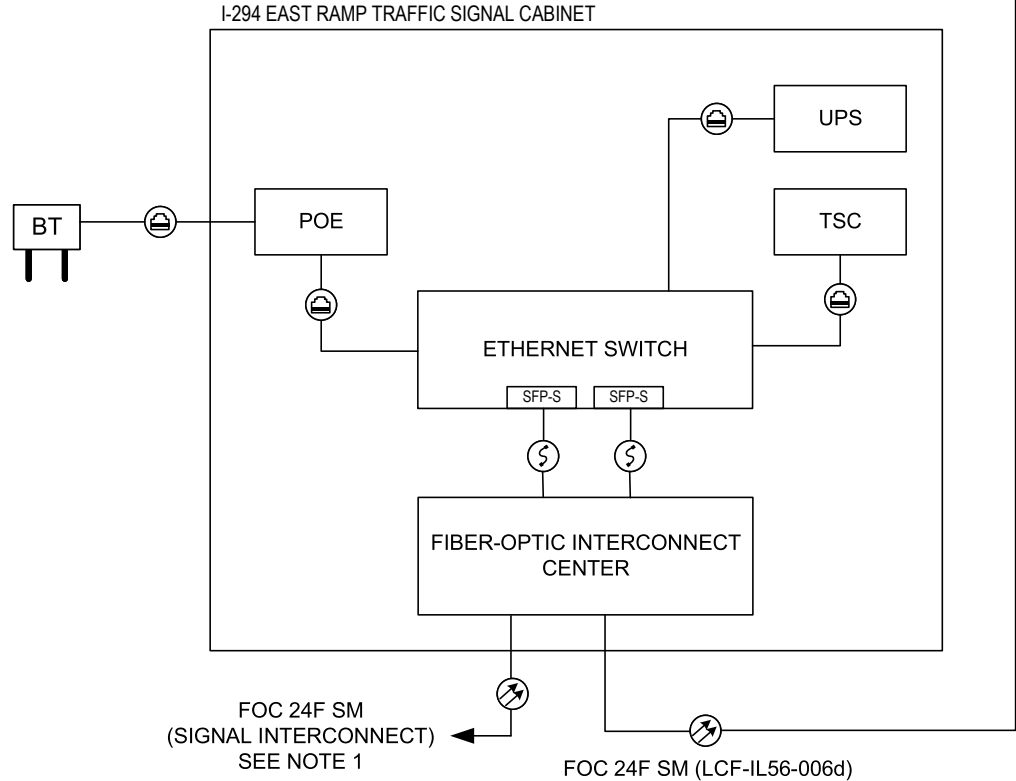



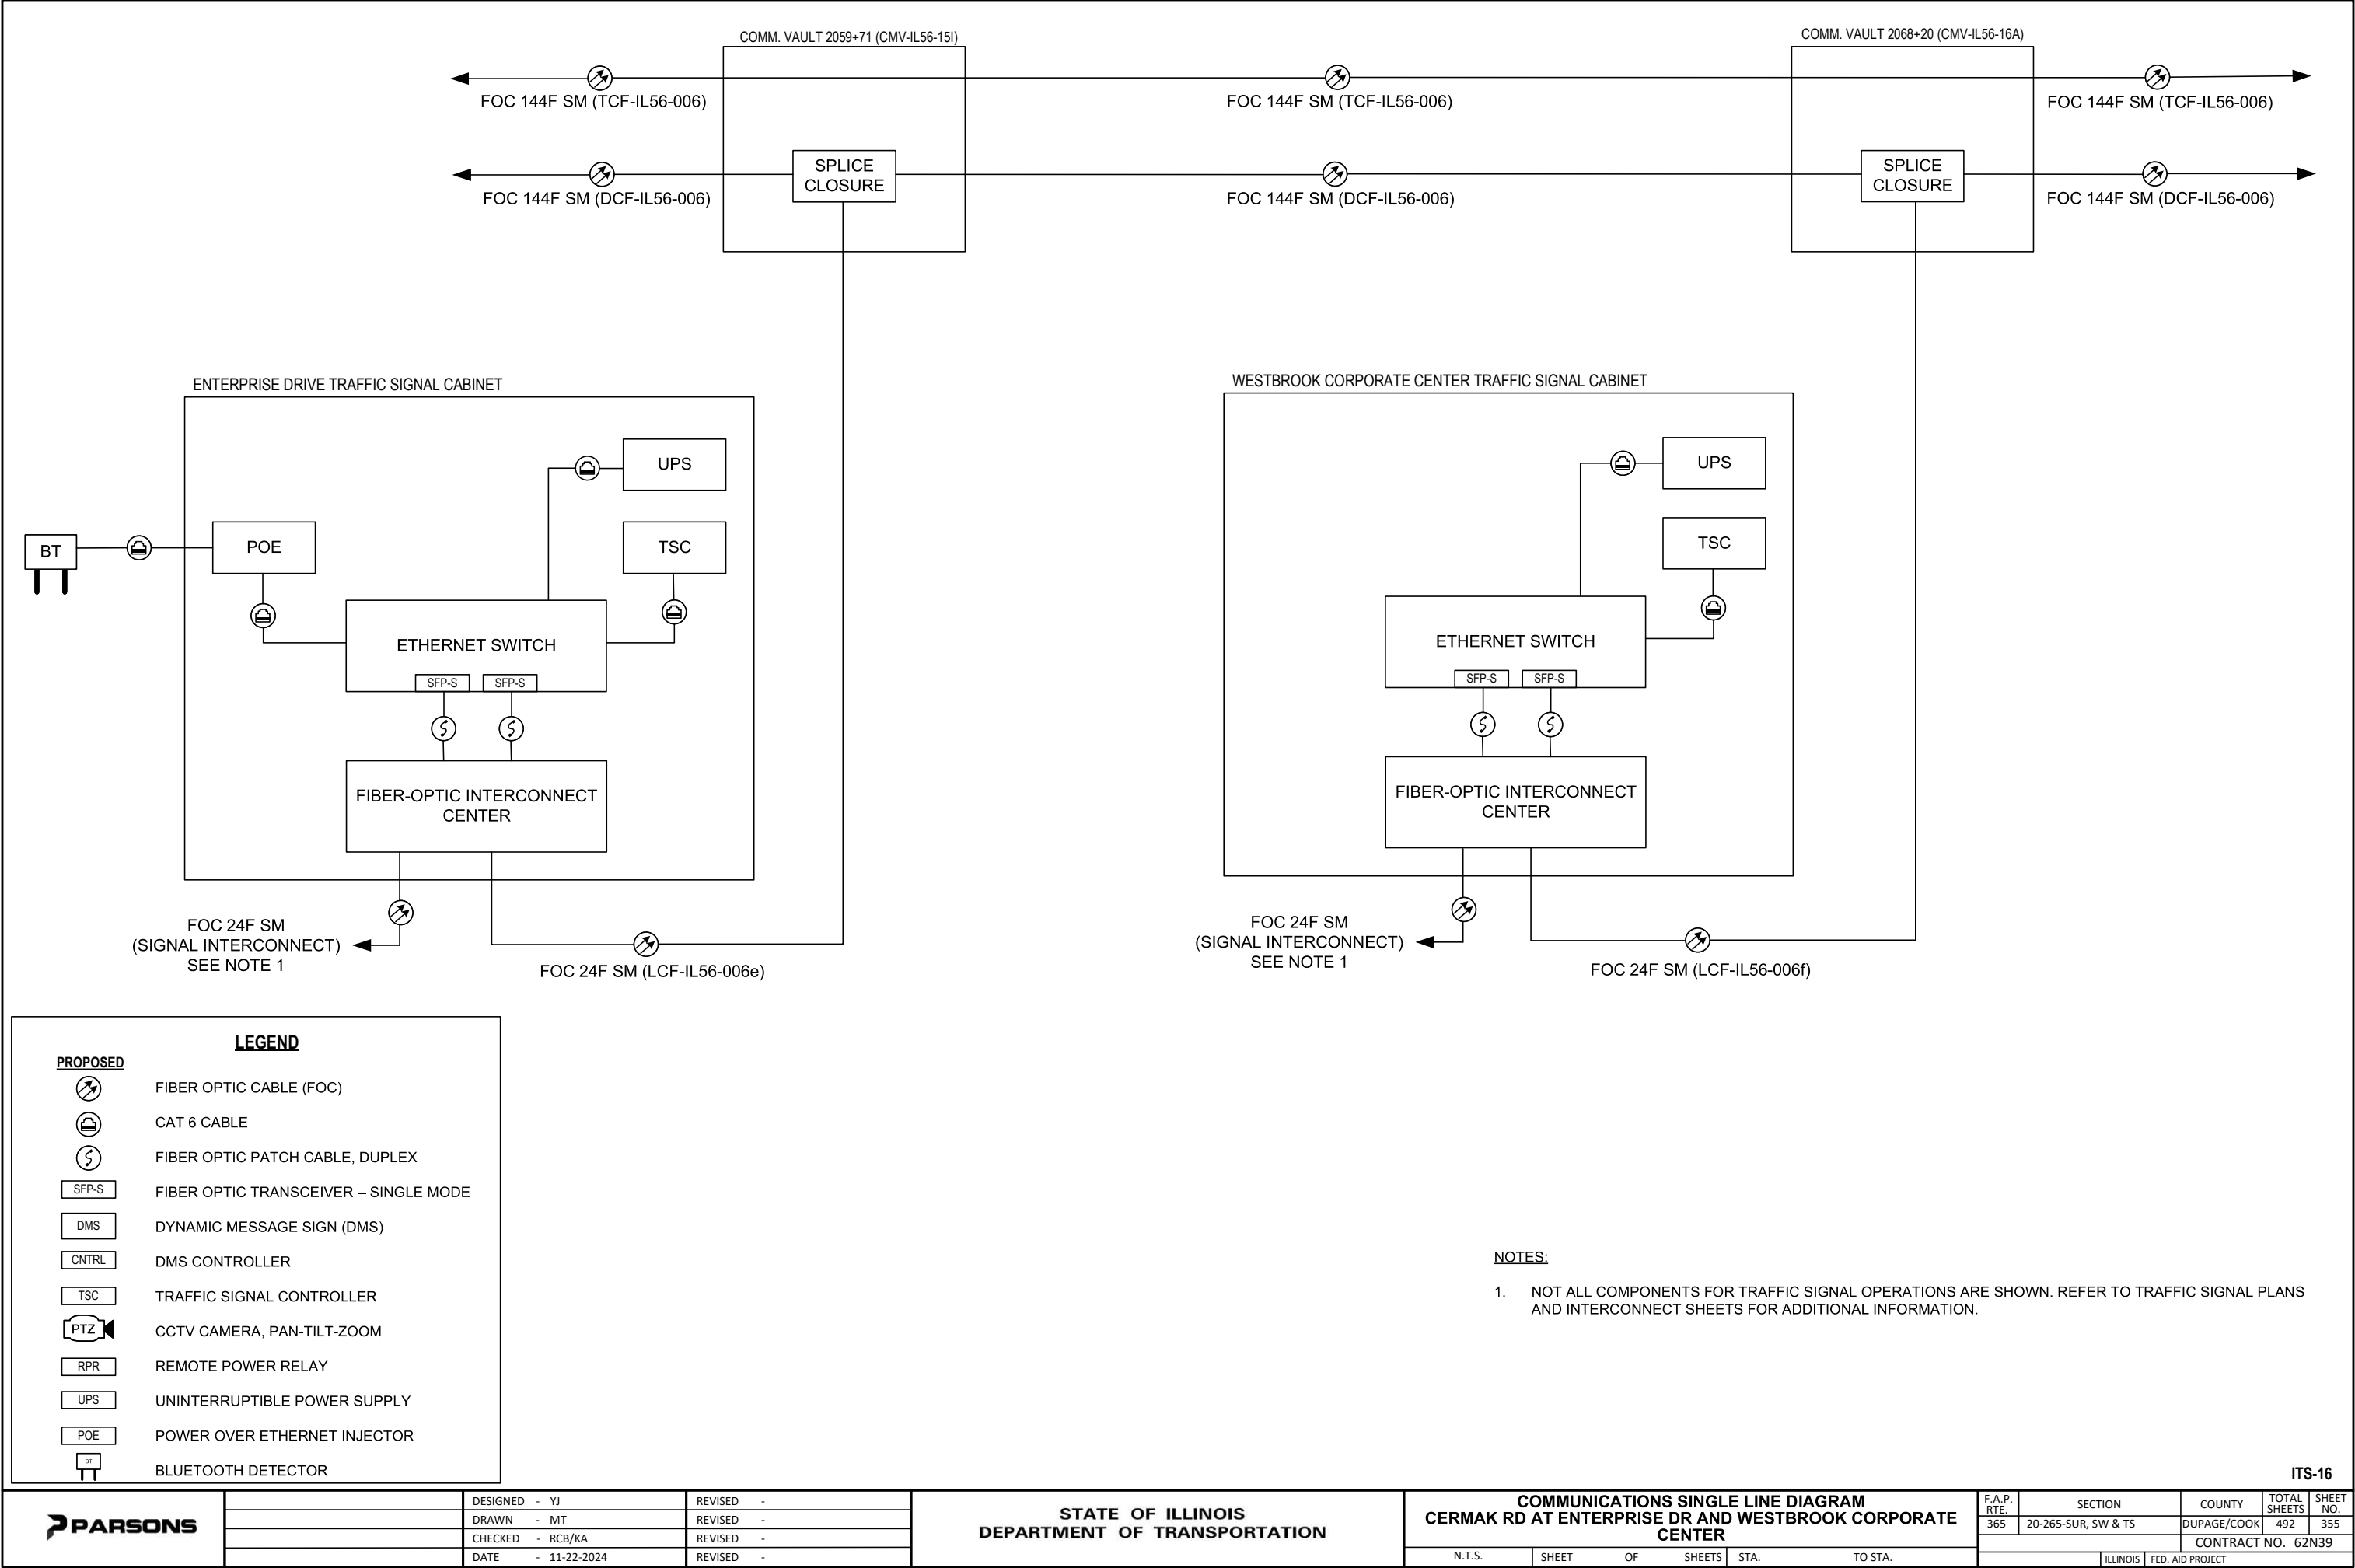



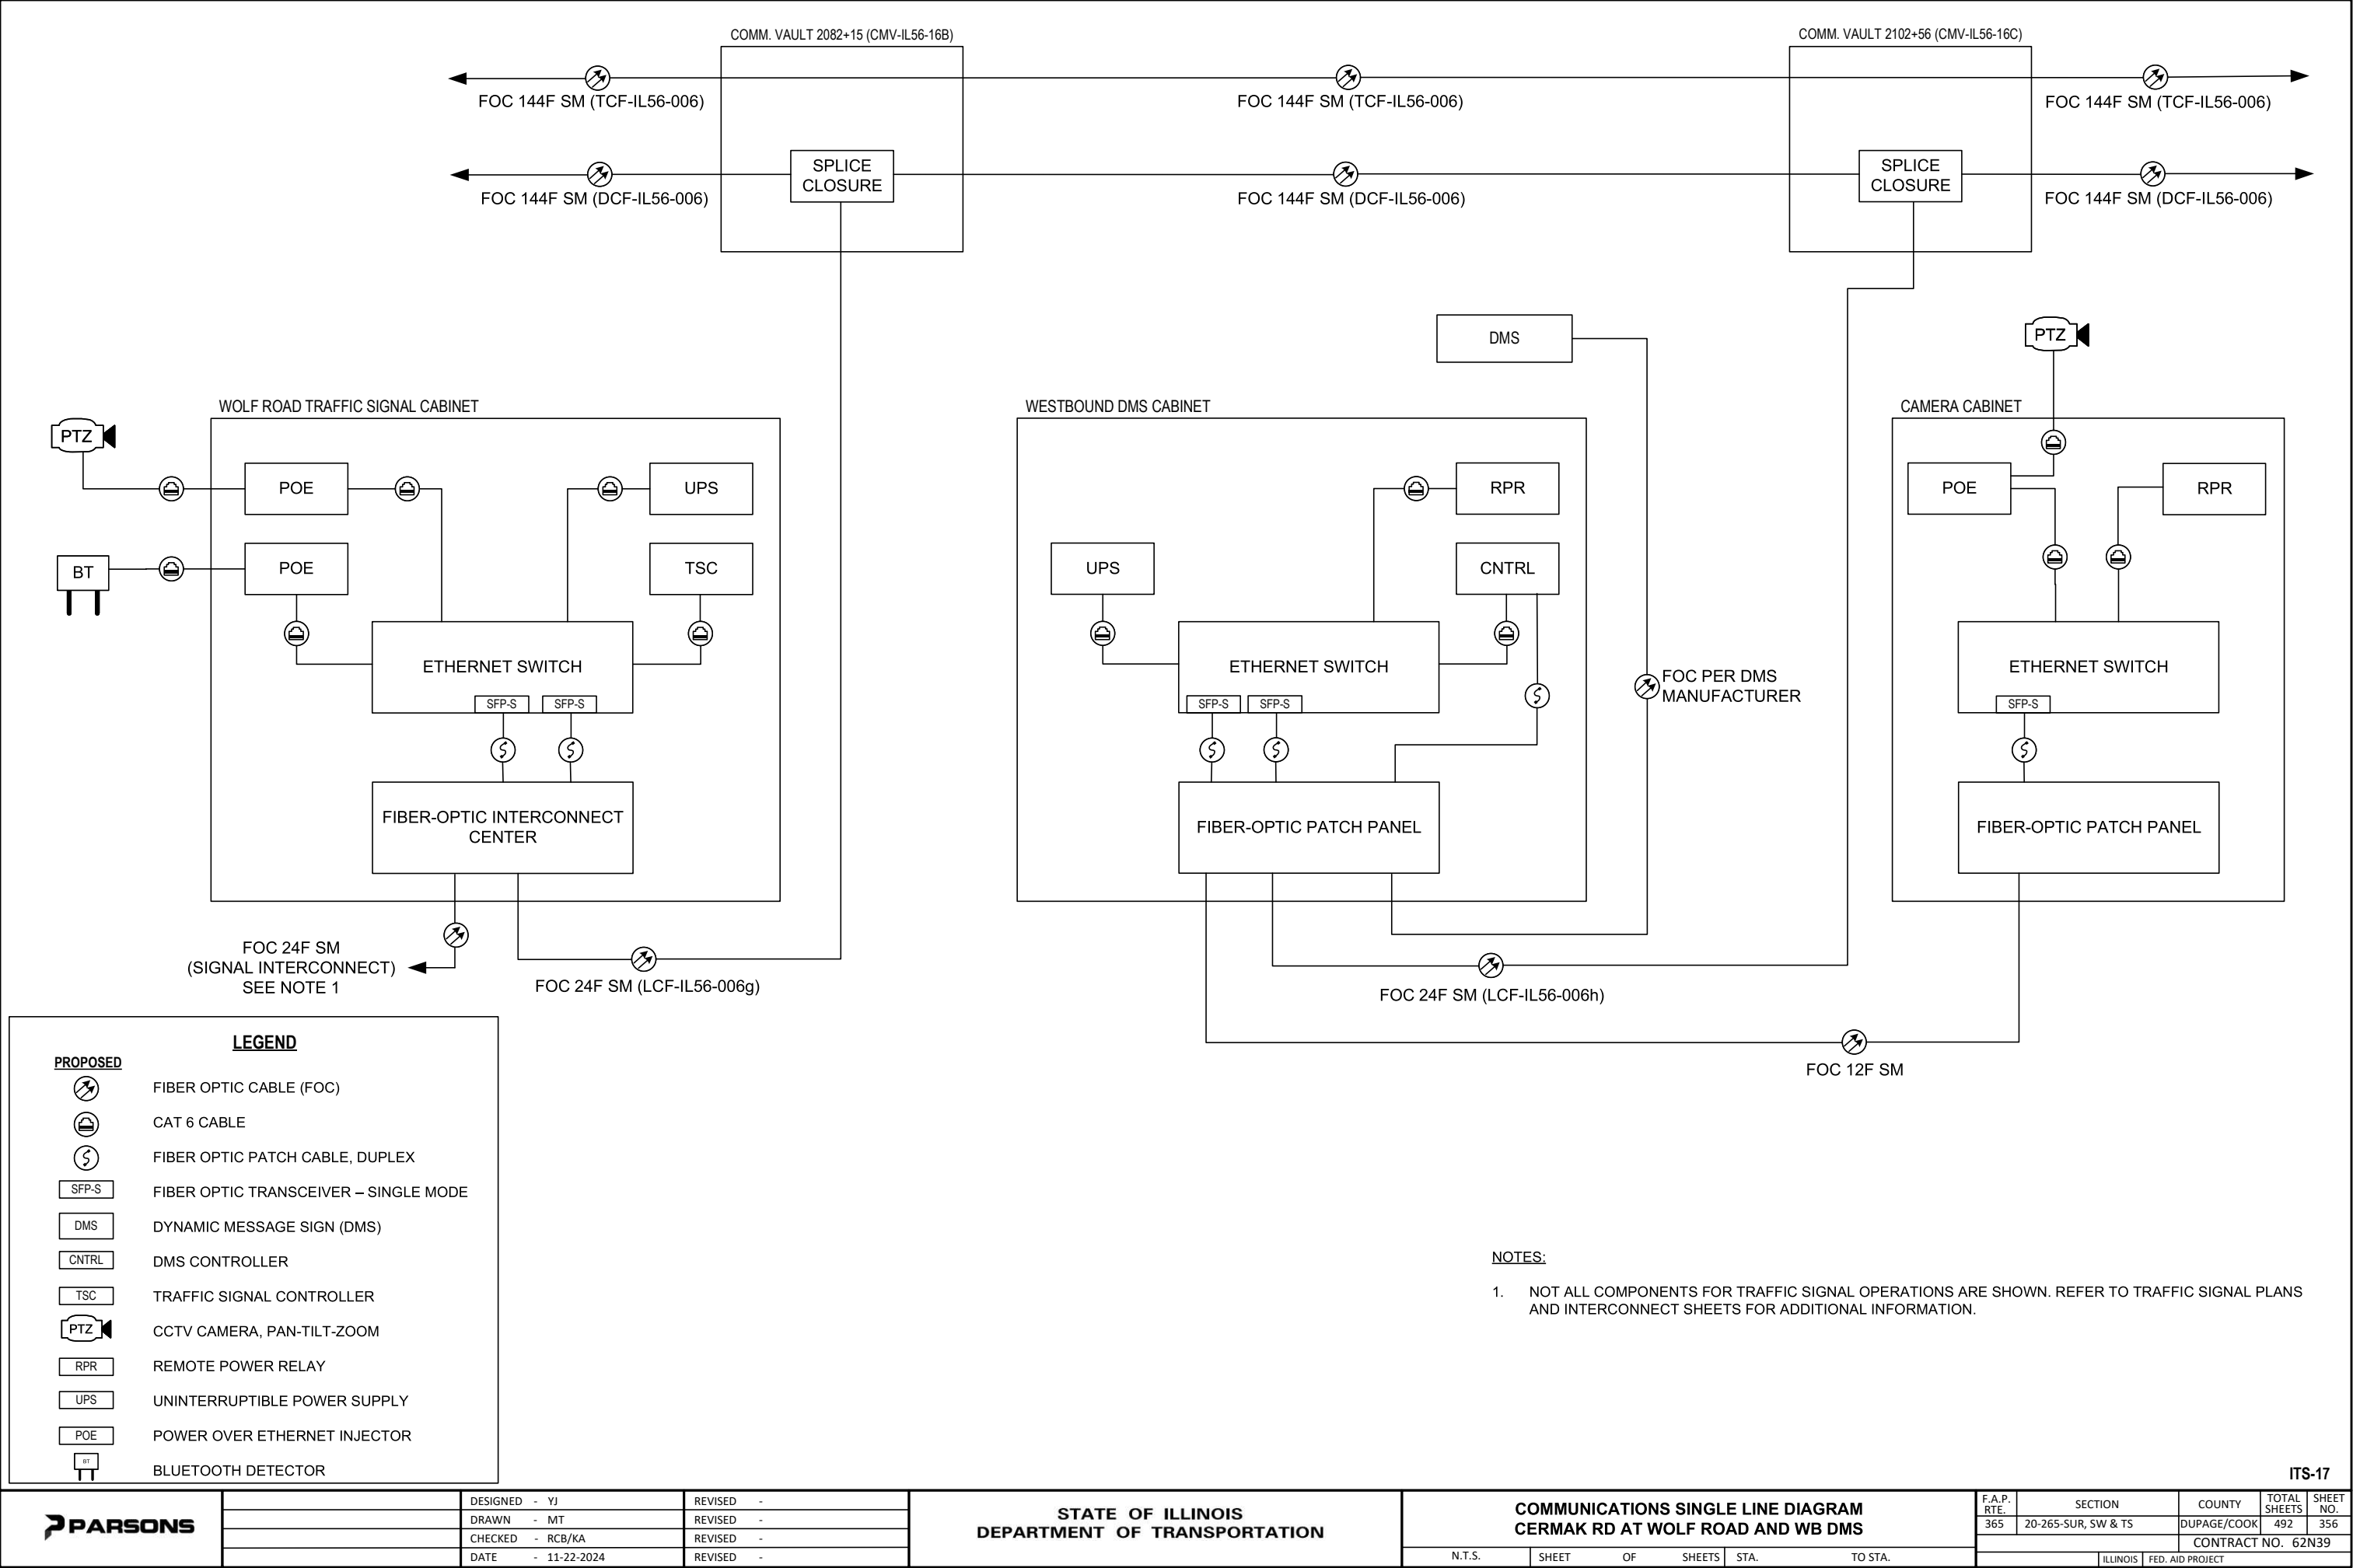

|                   |           |
|-------------------|-----------|
| DESIGNED - YJ     | REVISED - |
| DRAWN - MT        | REVISED - |
| CHECKED - RCB/KA  | REVISED - |
| DATE - 11-22-2024 | REVISED - |

STATE OF ILLINOIS  
DEPARTMENT OF TRANSPORTATION

COMMUNICATIONS SINGLE LINE DIAGRAM  
CERMAK RD AT WOLF ROAD AND WB DMS

N.T.S.

SHEET

OF


SHEETS


STA.

TO STA.

|             |                     |                  |              |                    |
|-------------|---------------------|------------------|--------------|--------------------|
| F.A.P. RTE. | SECTION             | COUNTY           | TOTAL SHEETS | SHEET NO.          |
| 365         | 20-265-SUR, SW & TS | DUPAGE/COOK      | 492          | 356                |
|             |                     |                  |              | CONTRACT NO. 62N39 |
| ILLINOIS    |                     | FED. AID PROJECT |              |                    |

ITS-17

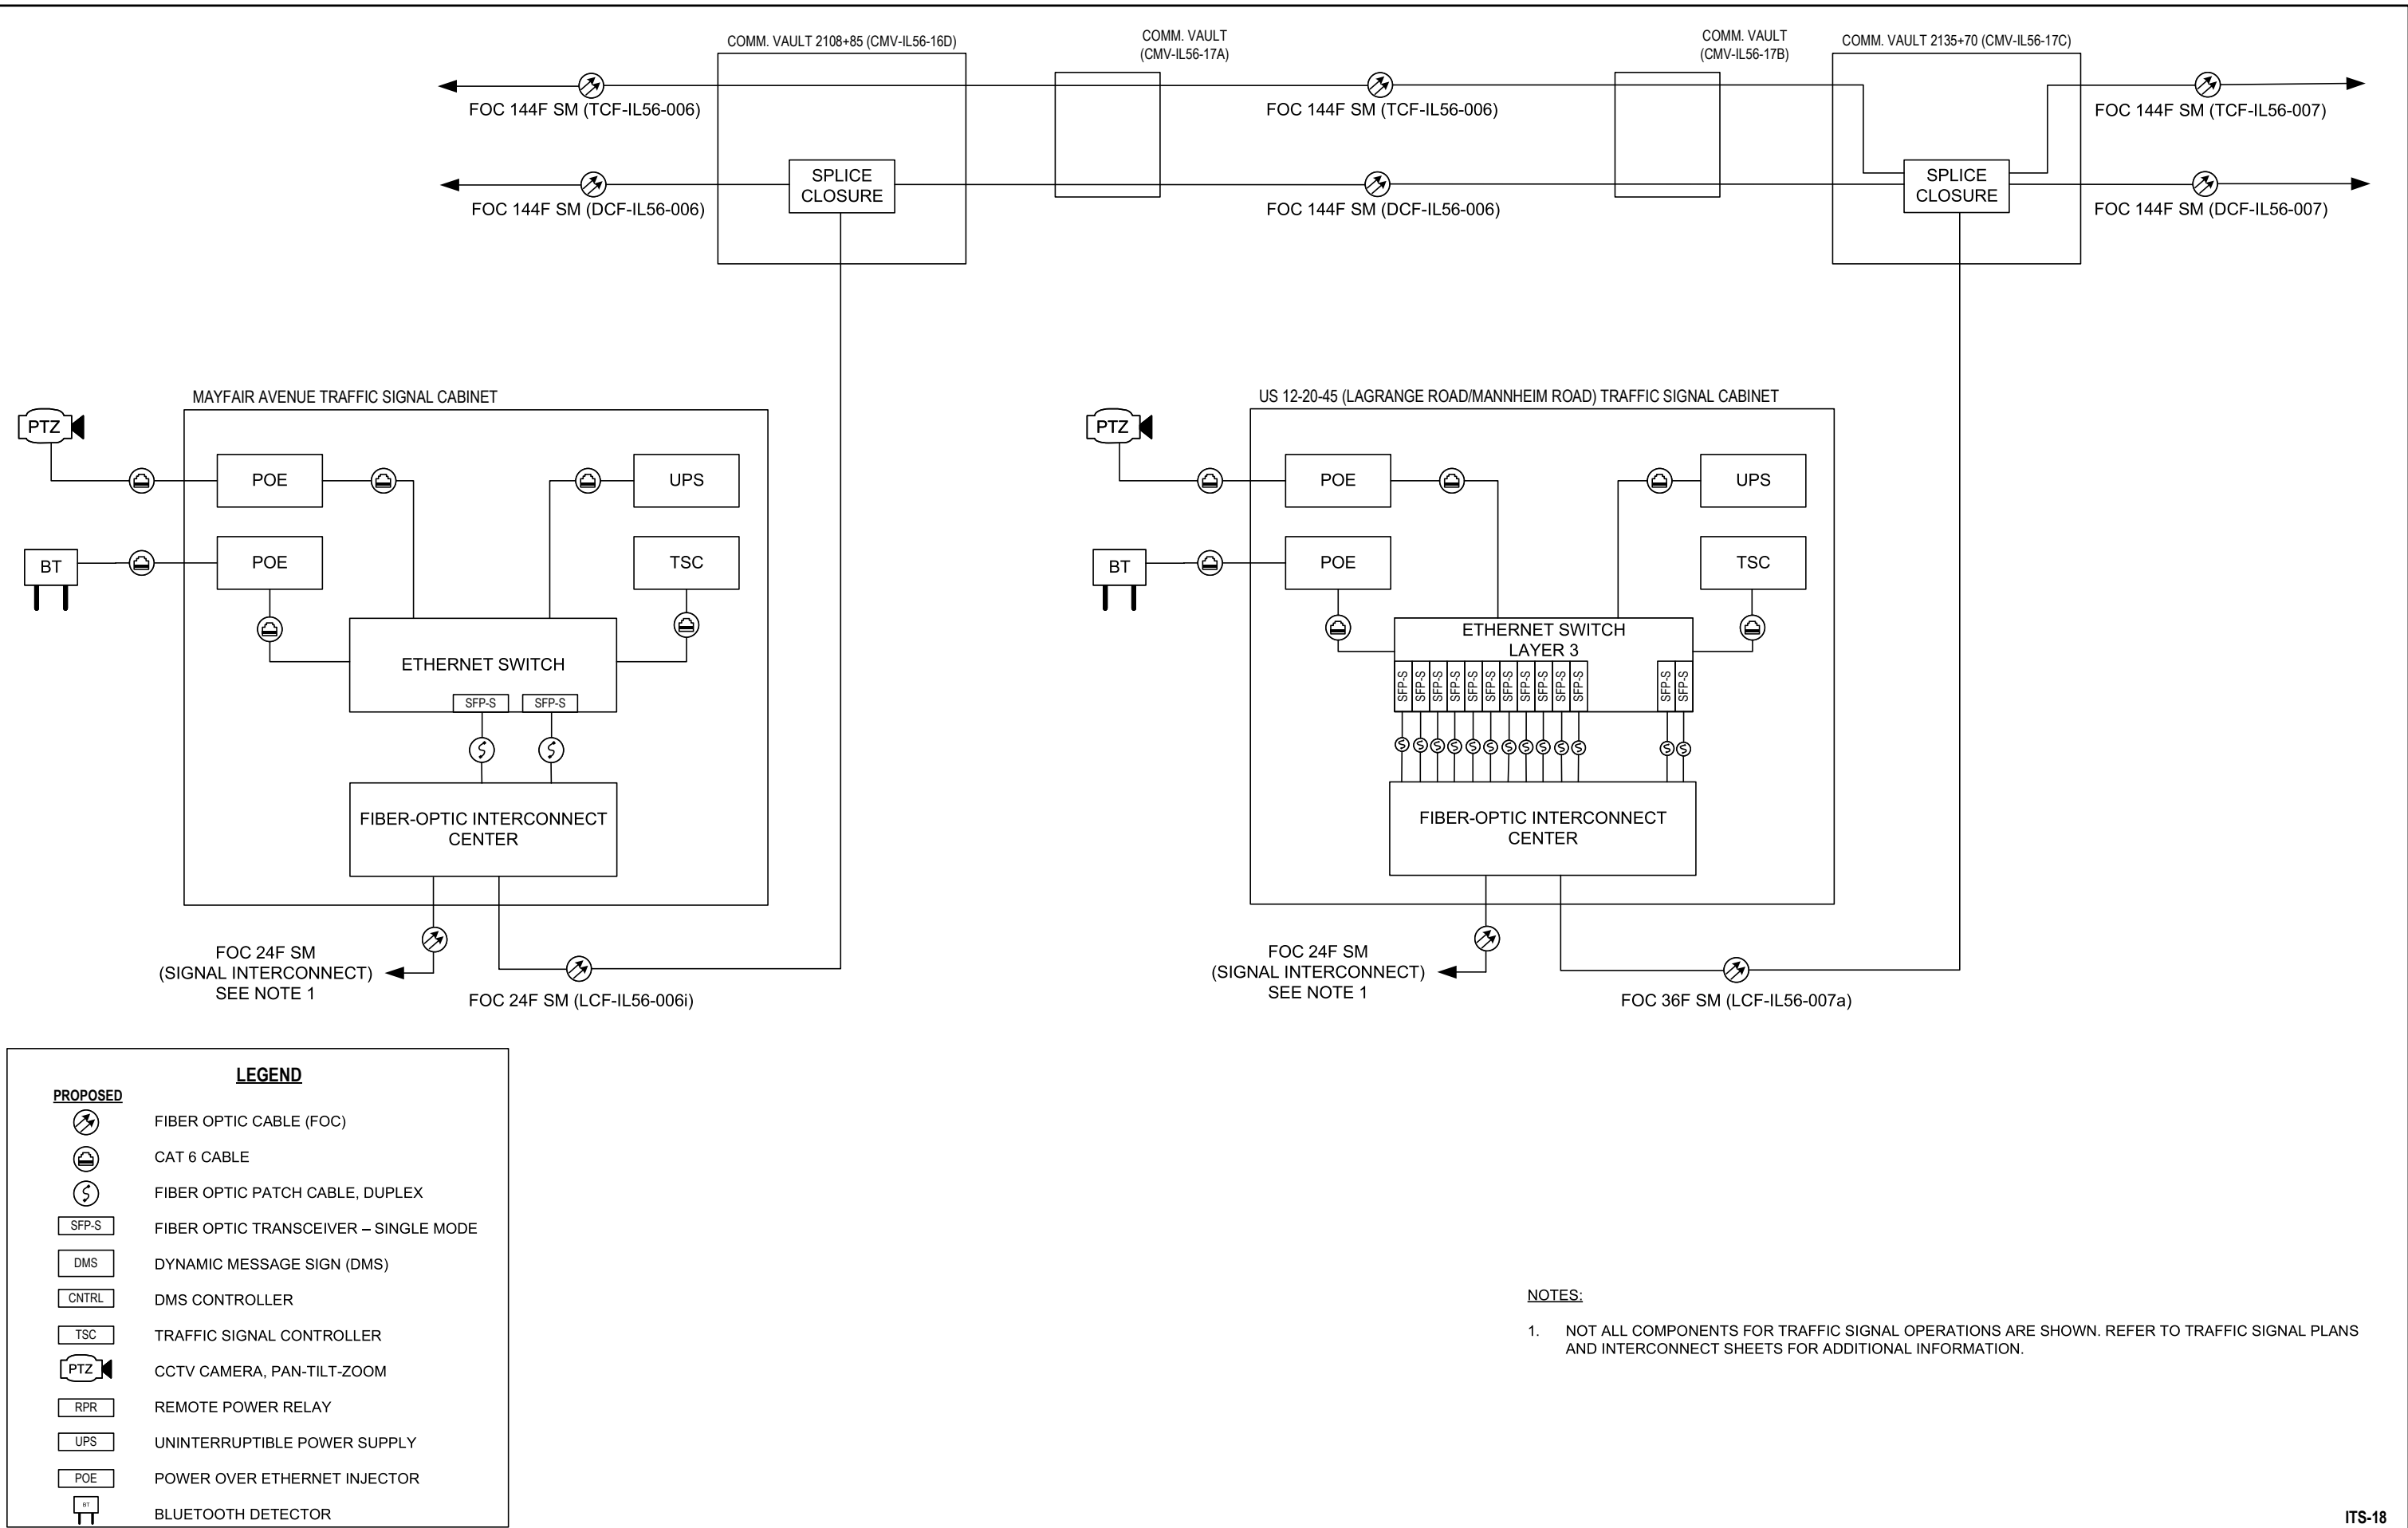

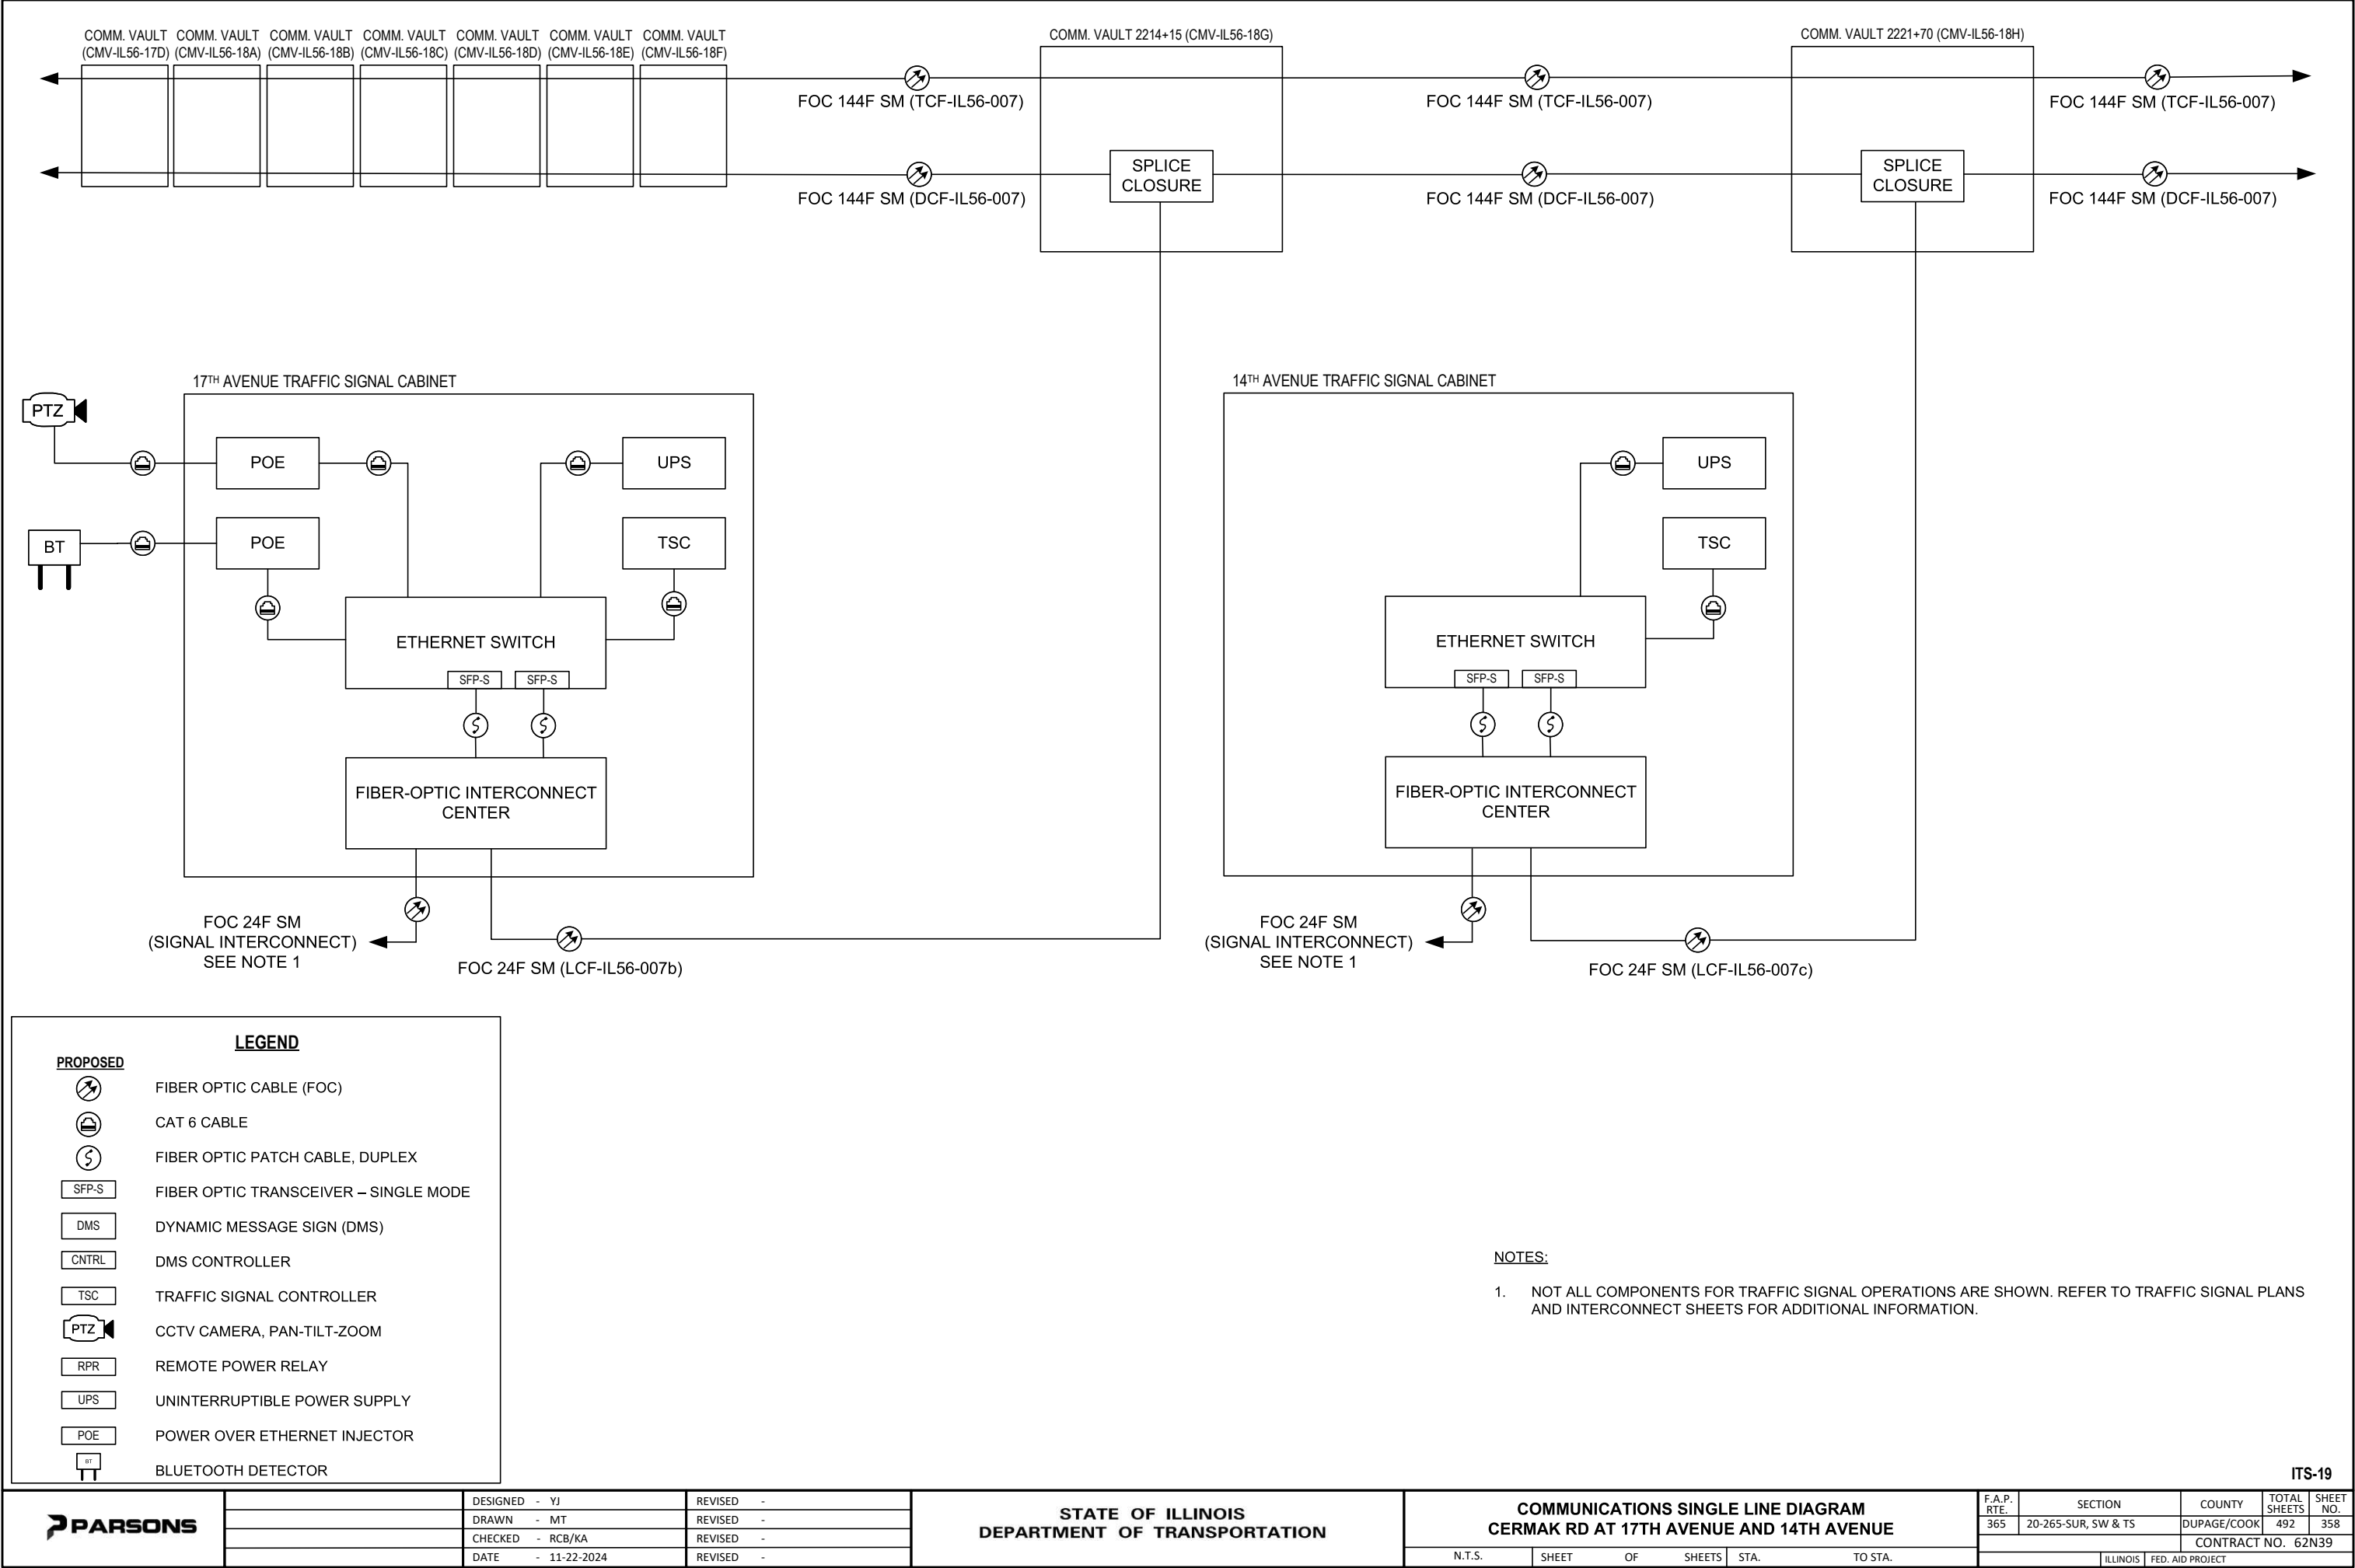

|                   |           |
|-------------------|-----------|
| DESIGNED - YJ     | REVISED - |
| DRAWN - MT        | REVISED - |
| CHECKED - RCB/KA  | REVISED - |
| DATE - 11-22-2024 | REVISED - |

STATE OF ILLINOIS

DEPARTMENT OF TRANSPORTATION

COMMUNICATIONS SINGLE LINE DIAGRAM

CERMAK RD AT 17TH AVENUE AND 14TH AVENUE

N.T.S.

SHEET

OF


SHEETS


STA.

TO STA.

|             |                     |             |                  |                    |
|-------------|---------------------|-------------|------------------|--------------------|
| F.A.P. RTE. | SECTION             | COUNTY      | TOTAL SHEETS     | SHEET NO.          |
| 365         | 20-265-SUR, SW & TS | DUPAGE/COOK | 492              | 358                |
|             |                     |             |                  | CONTRACT NO. 62N39 |
|             |                     | ILLINOIS    | FED. AID PROJECT |                    |

ITS-19

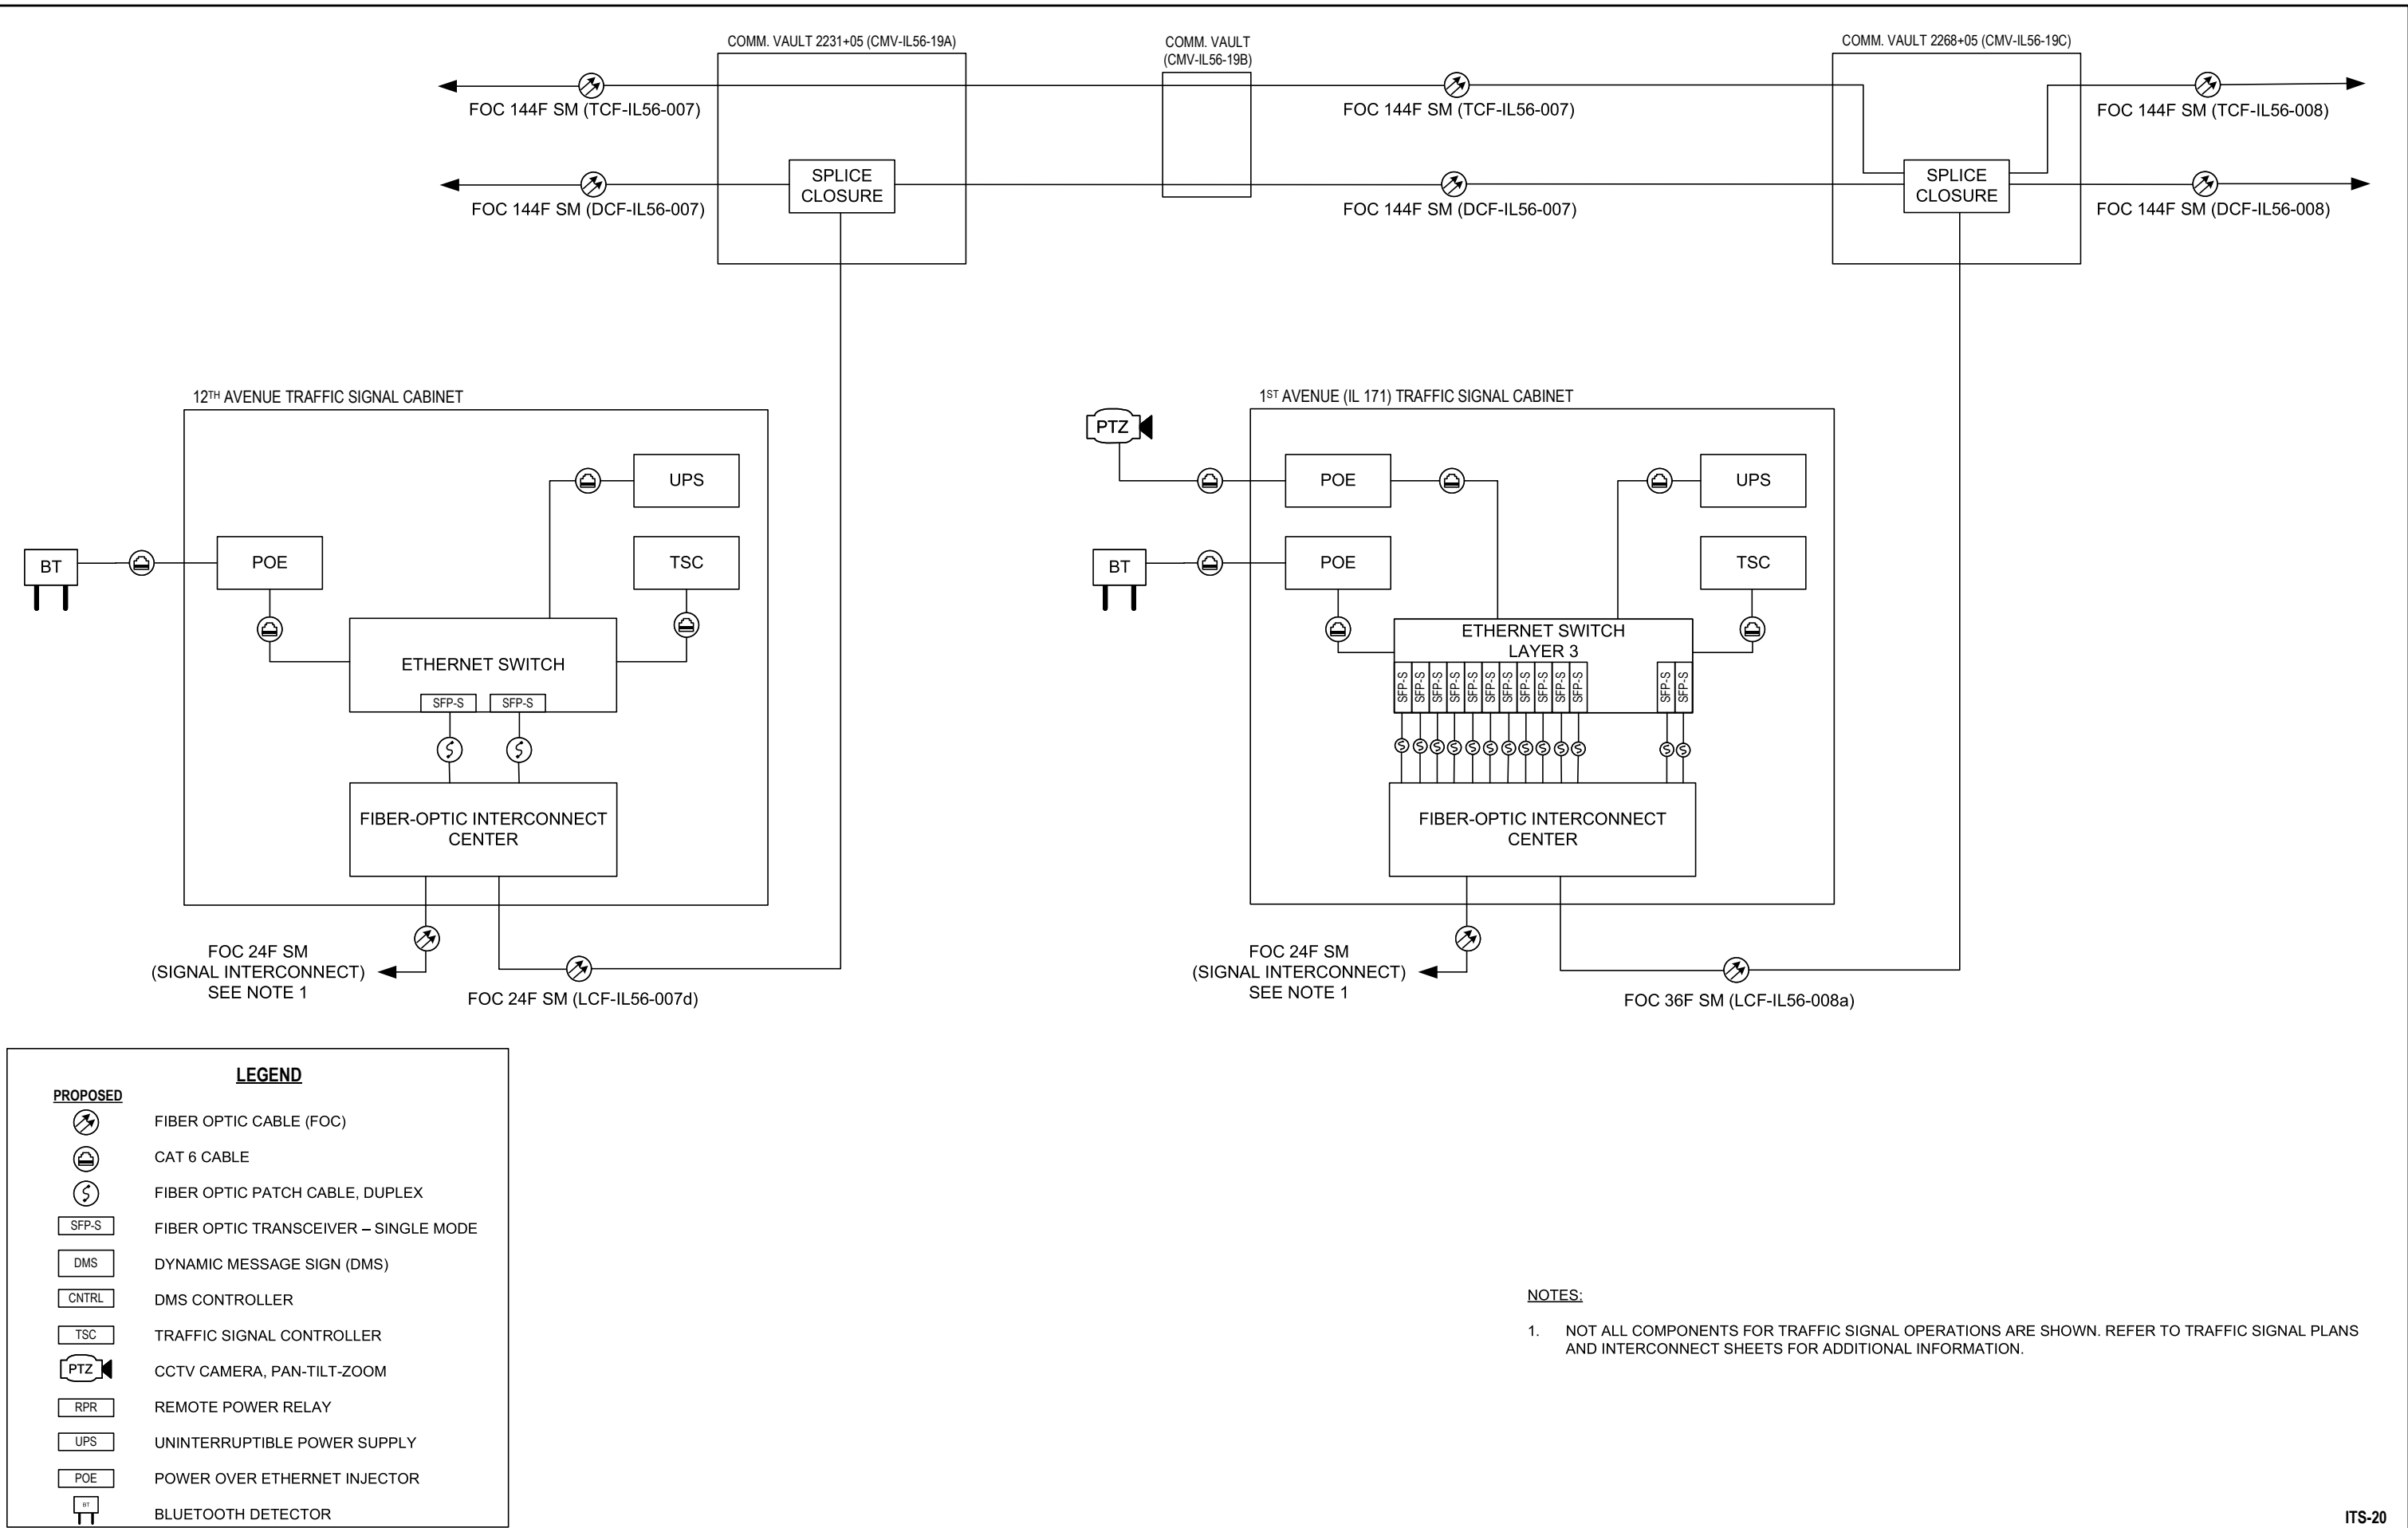

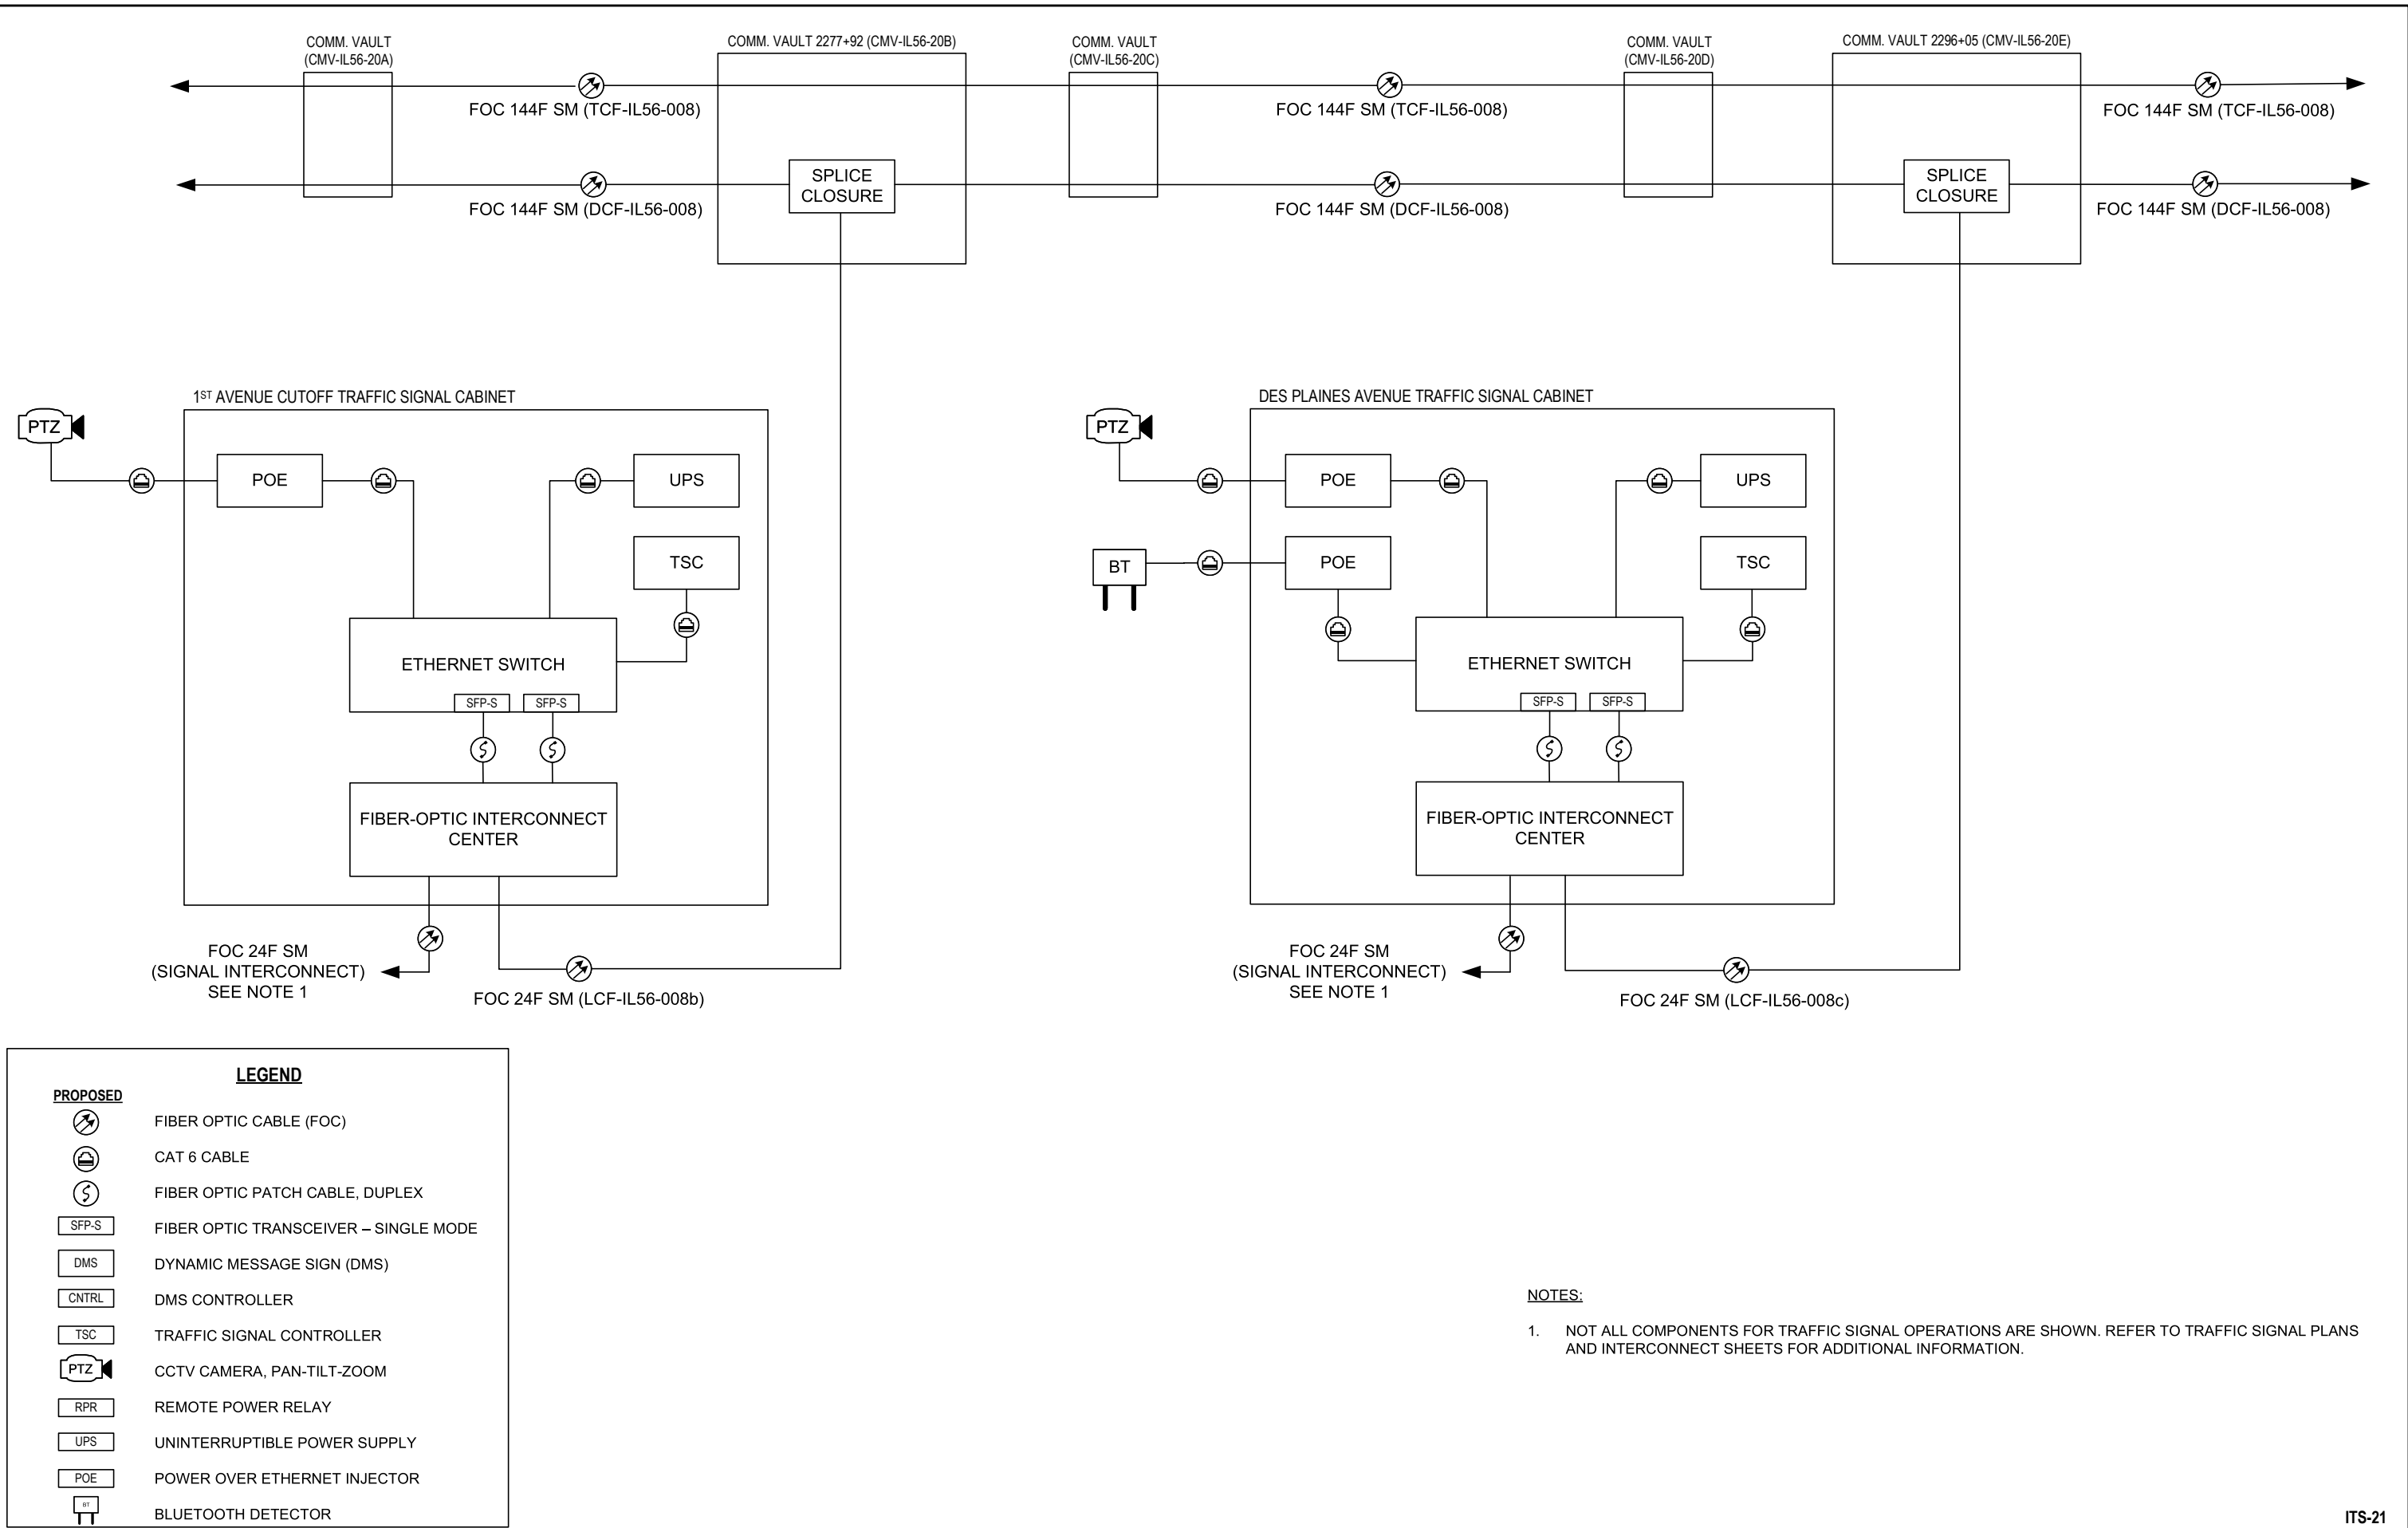

PROPOSED

FIBER OPTIC CABLE (FOC)

CAT 6 CABLE

FIBER OPTIC PATCH CABLE, DUPLEX

FIBER OPTIC TRANSCEIVER – SINGLE MODE

DYNAMIC MESSAGE SIGN (DMS)

DMS CONTROLLER

TRAFFIC SIGNAL CONTROLLER

CCTV CAMERA, PAN-TILT-ZOOM

REMOTE POWER RELAY


UNINTERRUPTIBLE POWER SUPPLY

POWER OVER ETHERNET INJECTOR


BLUETOOTH DETECTOR

LEGEND

- NOTES:
1. NOT ALL COMPONENTS FOR TRAFFIC SIGNAL OPERATIONS ARE SHOWN. REFER TO TRAFFIC SIGNAL PLANS AND INTERCONNECT SHEETS FOR ADDITIONAL INFORMATION.

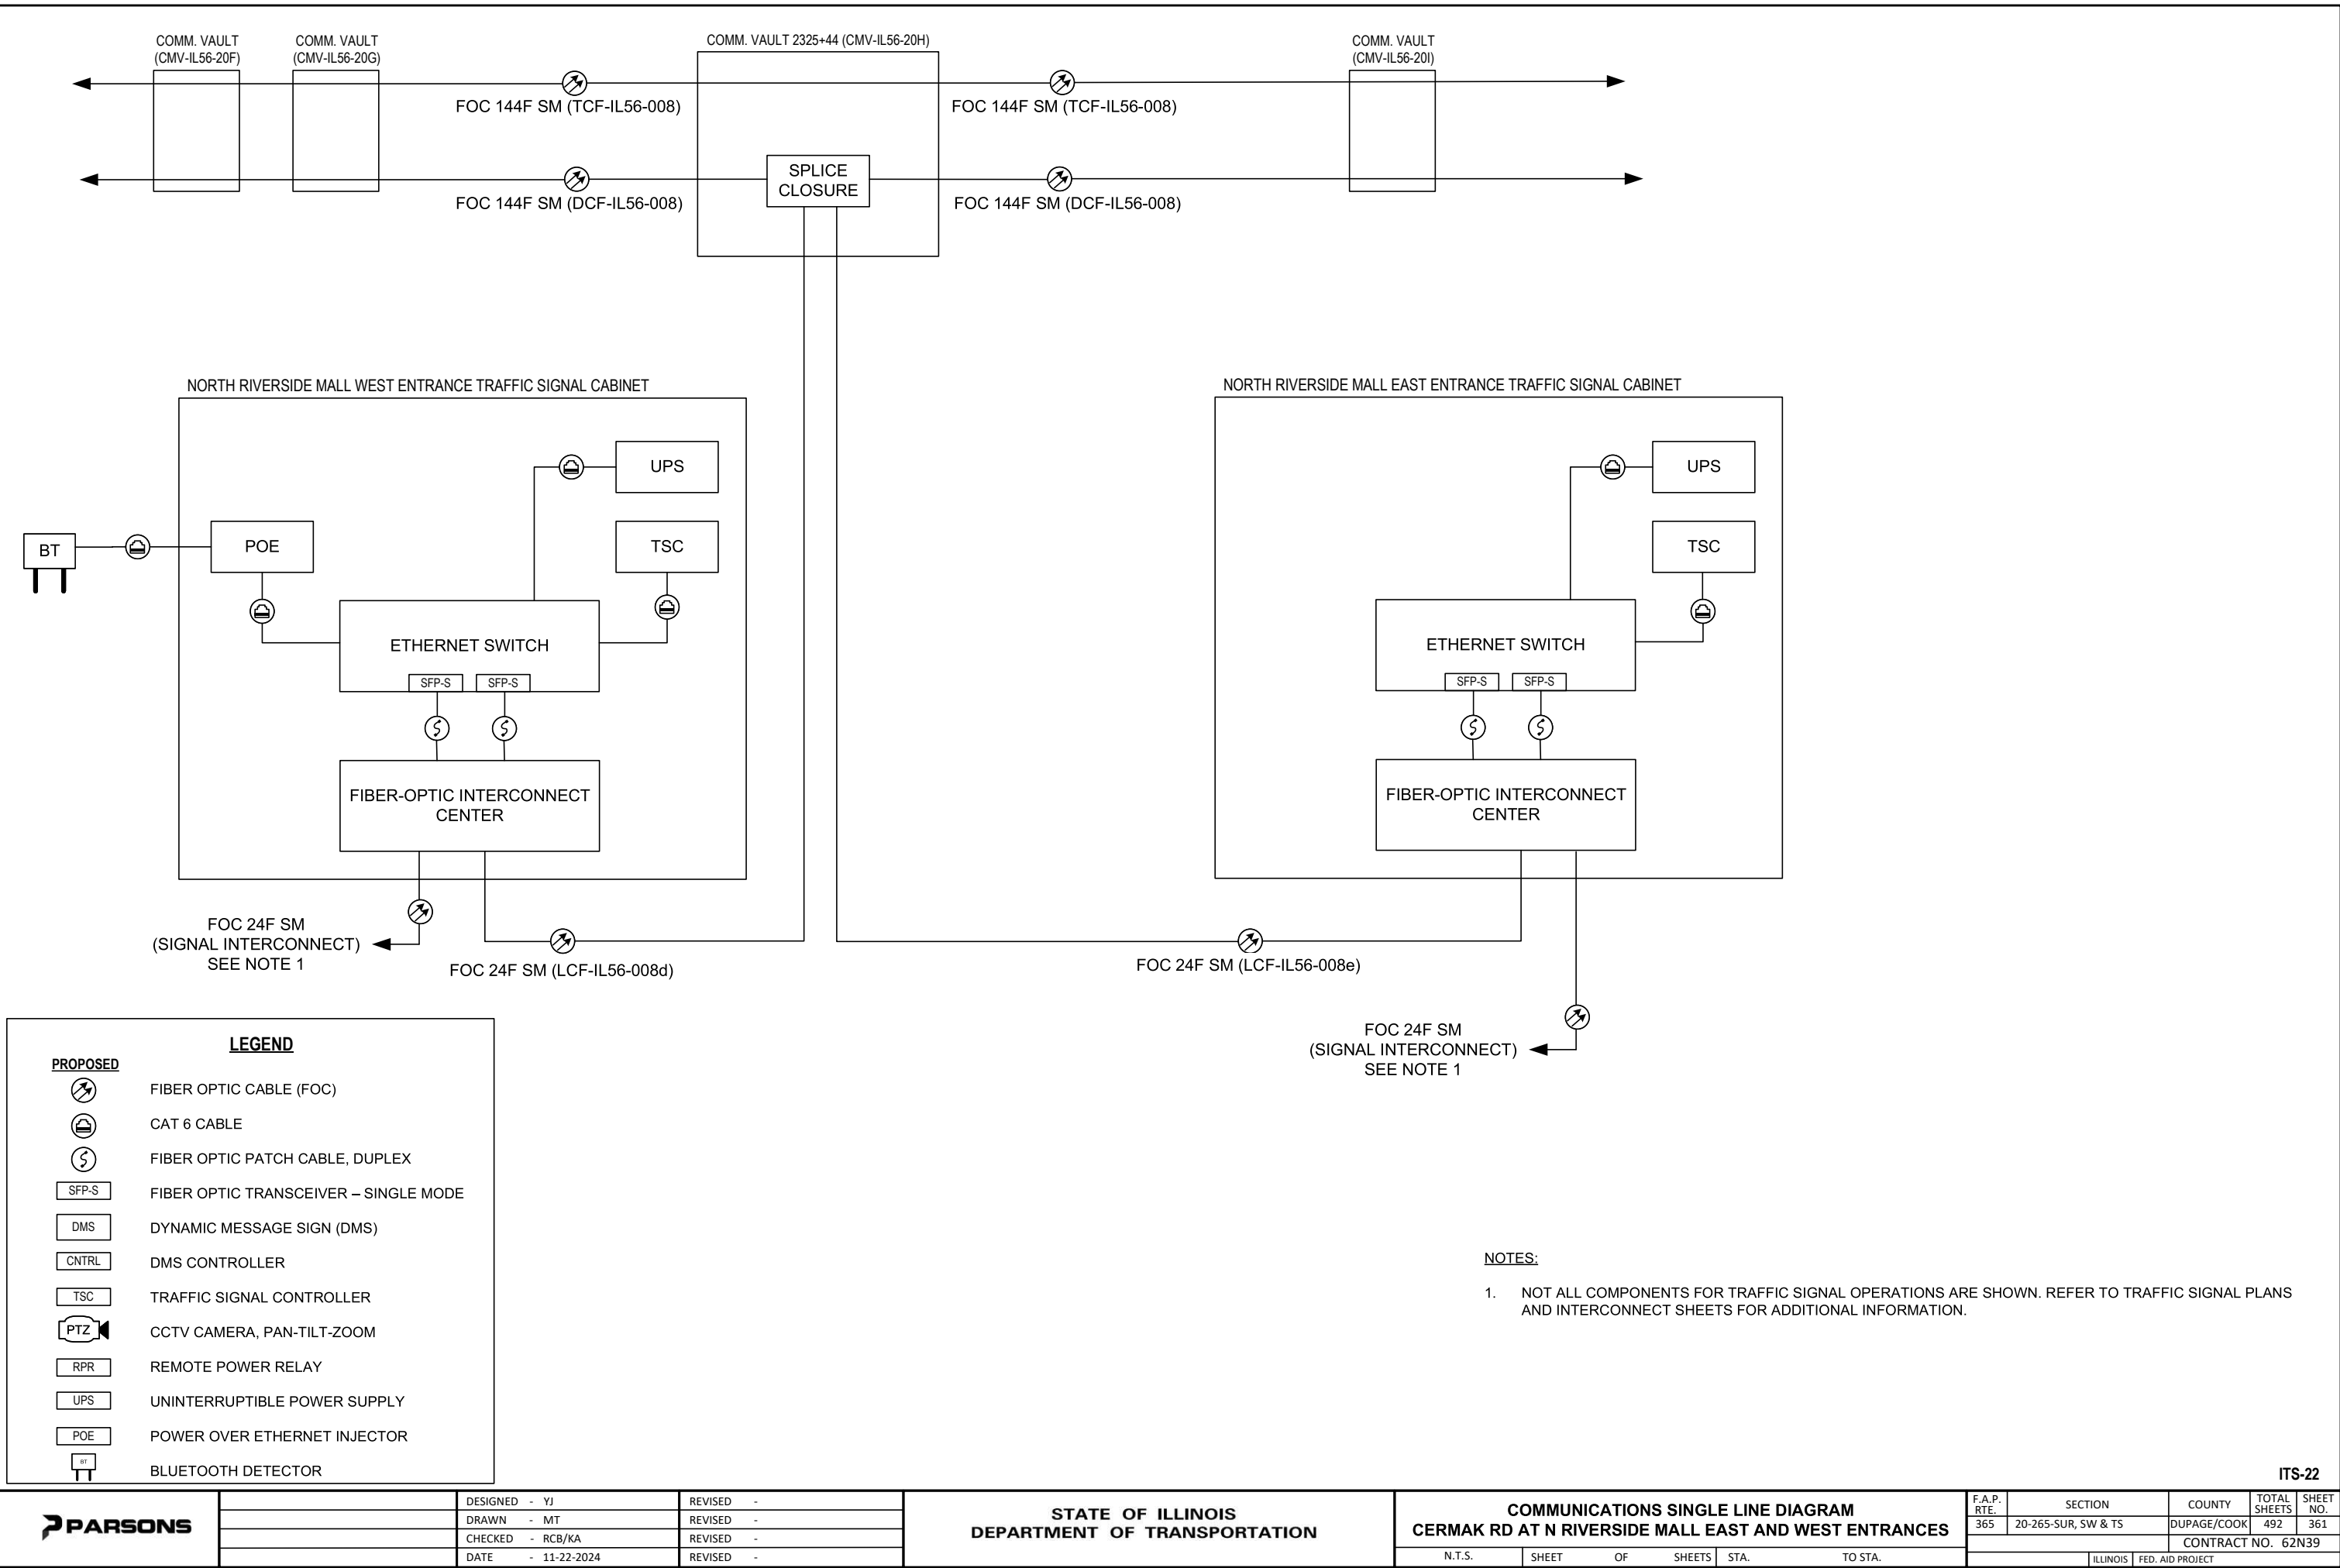



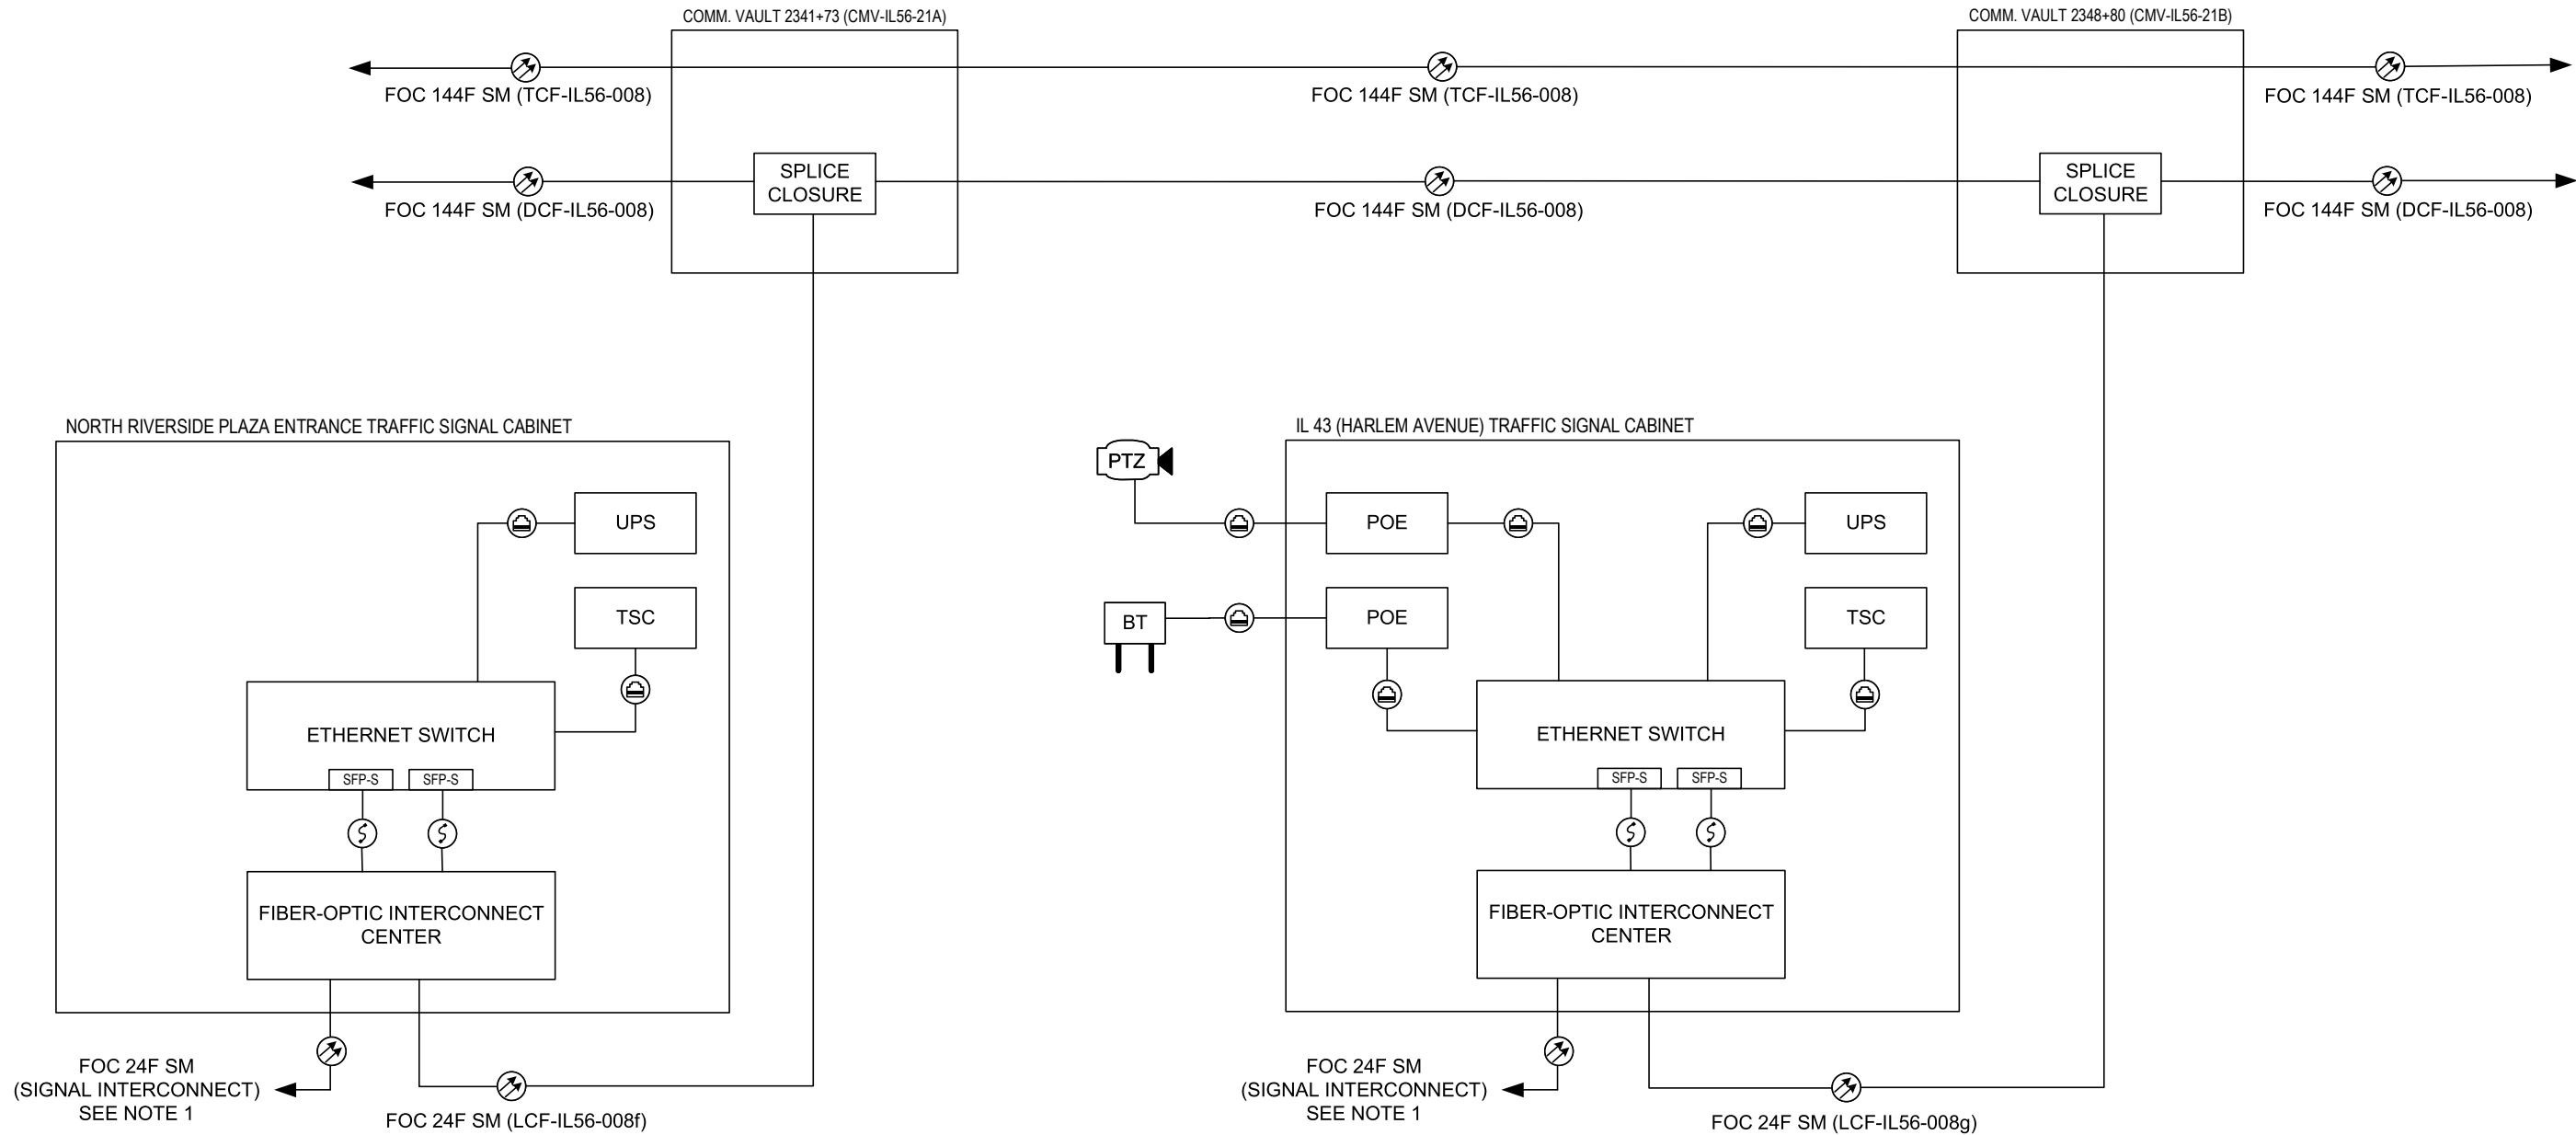

| LEGEND |                                       |
|--------|---------------------------------------|
|        | FIBER OPTIC CABLE (FOC)               |
|        | CAT 6 CABLE                           |
|        | FIBER OPTIC PATCH CABLE, DUPLEX       |
|        | FIBER OPTIC TRANSCEIVER – SINGLE MODE |
|        | DYNAMIC MESSAGE SIGN (DMS)            |
|        | DMS CONTROLLER                        |
|        | TRAFFIC SIGNAL CONTROLLER             |
|        | CCTV CAMERA, PAN-TILT-ZOOM            |
|        | REMOTE POWER RELAY                    |
|        | UNINTERRUPTIBLE POWER SUPPLY          |
|        | POWER OVER ETHERNET INJECTOR          |
|        | BLUETOOTH DETECTOR                    |

- NOTES:
- NOT ALL COMPONENTS FOR TRAFFIC SIGNAL OPERATIONS ARE SHOWN. REFER TO TRAFFIC SIGNAL PLANS AND INTERCONNECT SHEETS FOR ADDITIONAL INFORMATION.



|          |              |
|----------|--------------|
| DESIGNED | - YJ         |
| DRAWN    | - MT         |
| CHECKED  | - RCB/KA     |
| DATE     | - 11-22-2024 |


|         |   |
|---------|---|
| REVISED | - |
| REVISED | - |
| REVISED | - |
| REVISED | - |

STATE OF ILLINOIS  
DEPARTMENT OF TRANSPORTATION

COMMUNICATIONS SINGLE LINE DIAGRAM  
CERMAK RD AT N RIVERSIDE PLAZA ENTRANCE AND HARLEM AVE

|        |       |    |        |      |         |
|--------|-------|----|--------|------|---------|
| N.T.S. | SHEET | OF | SHEETS | STA. | TO STA. |
|--------|-------|----|--------|------|---------|

| F.A.P. RTE.               | SECTION             | COUNTY      | TOTAL SHEETS | SHEET NO. |
|---------------------------|---------------------|-------------|--------------|-----------|
| 365                       | 20-265-SUR, SW & TS | DUPAGE/COOK | 492          | 362       |
| CONTRACT NO. 62N39        |                     |             |              |           |
| ILLINOIS FED. AID PROJECT |                     |             |              |           |

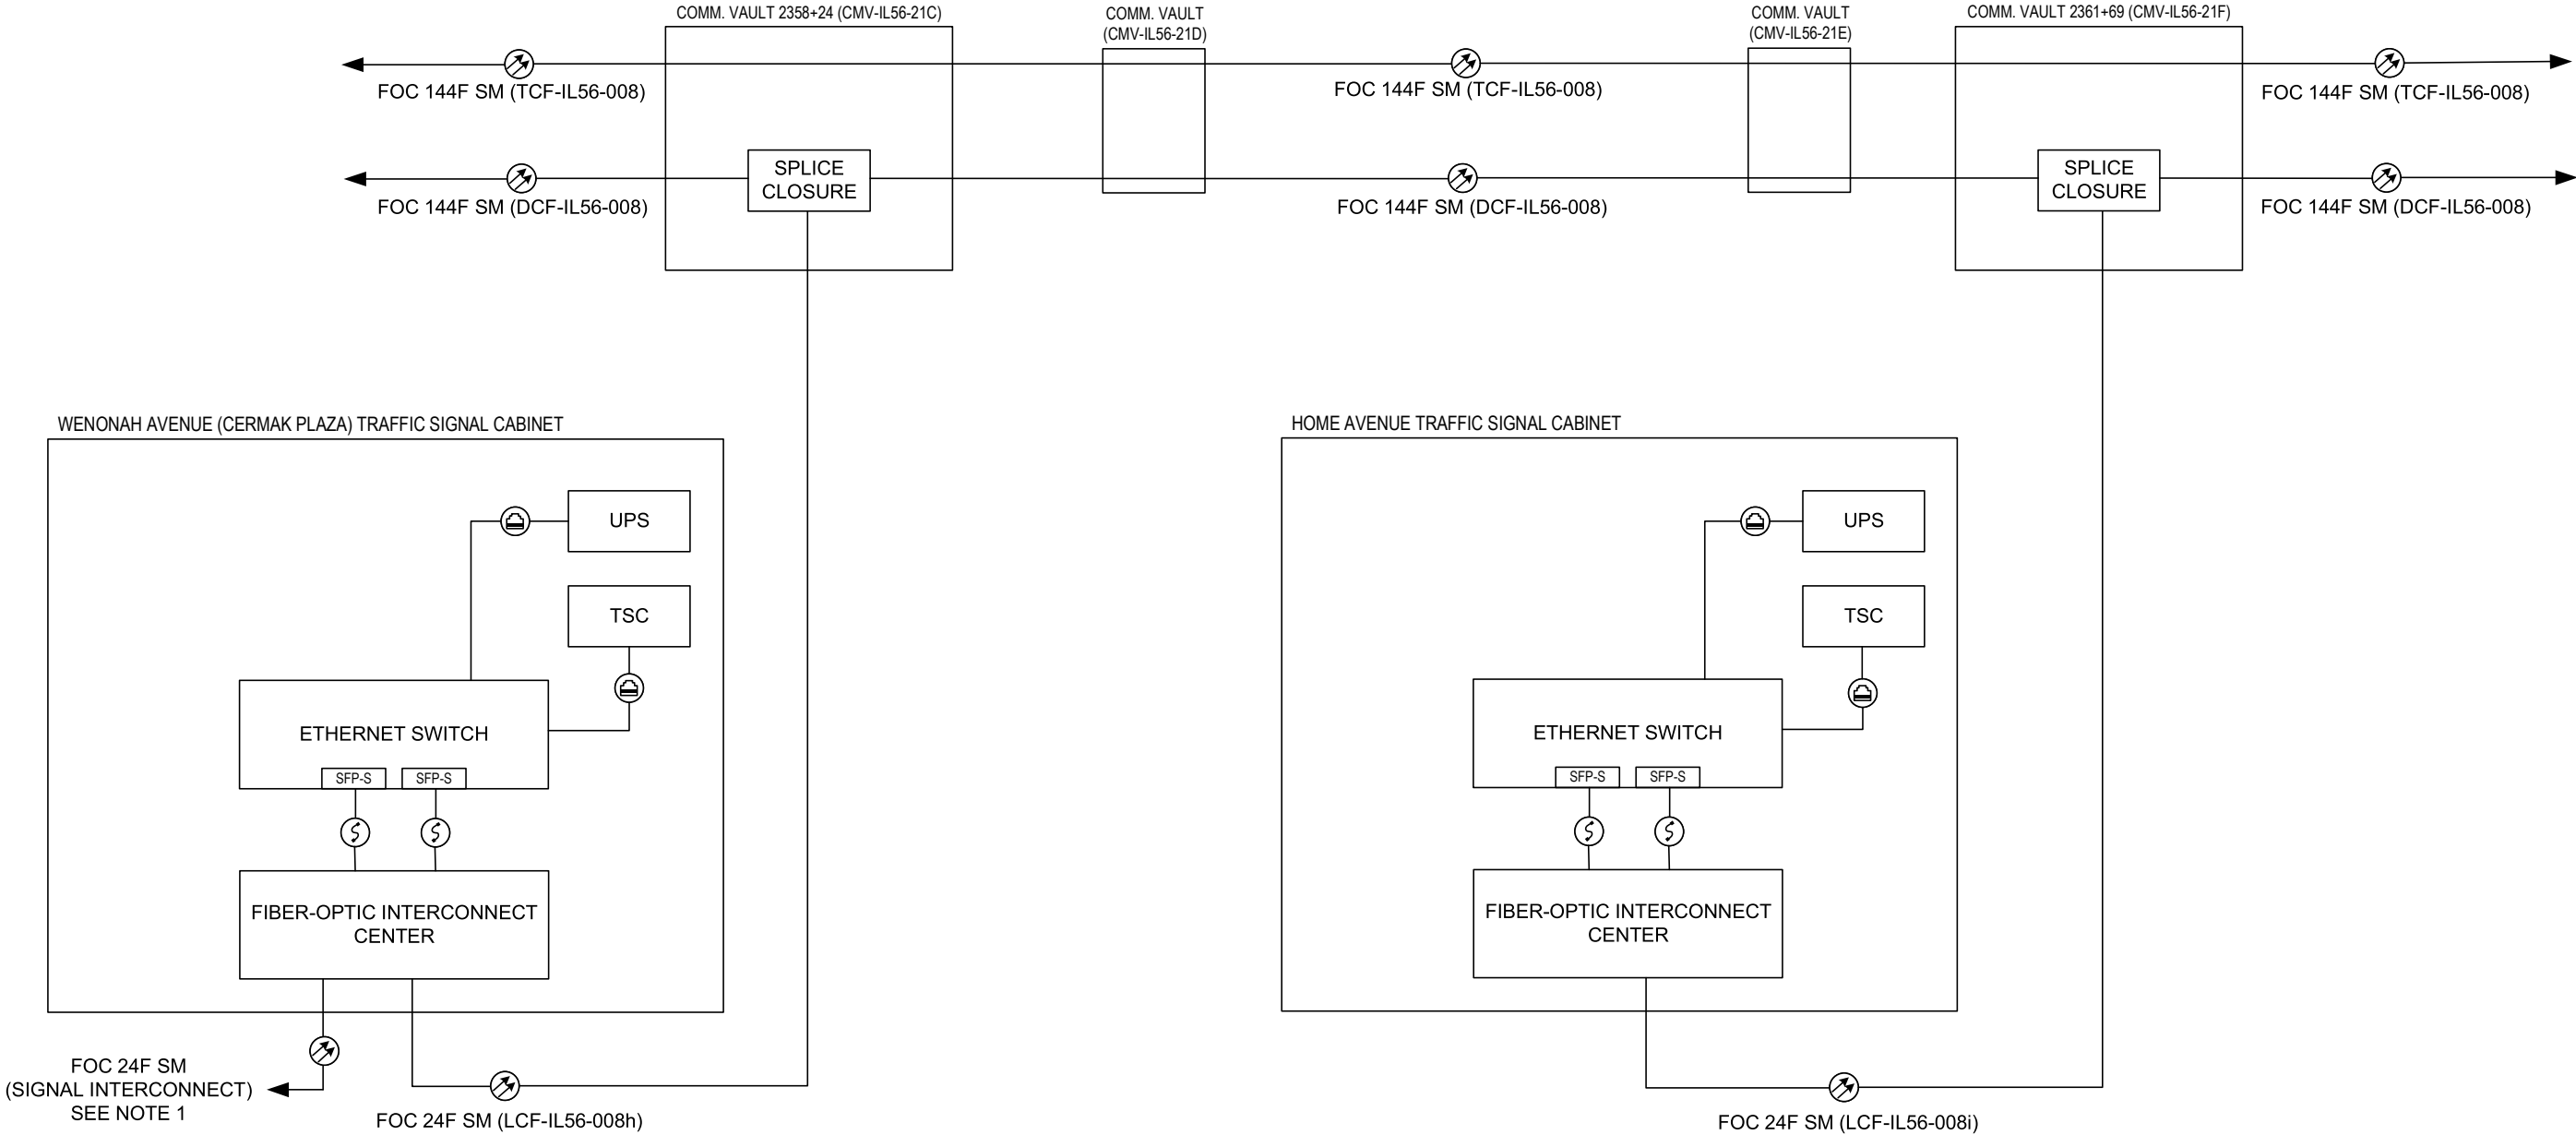

**PROPOSED**

FIBER OPTIC CABLE (FOC)

CAT 6 CABLE

FIBER OPTIC PATCH CABLE, DUPLEX

FIBER OPTIC TRANSCEIVER – SINGLE MODE

DYNAMIC MESSAGE SIGN (DMS)

DMS CONTROLLER

TRAFFIC SIGNAL CONTROLLER

CCTV CAMERA, PAN-TILT-ZOOM

REMOTE POWER RELAY

UNINTERRUPTIBLE POWER SUPPLY


POWER OVER ETHERNET INJECTOR


BLUETOOTH DETECTOR

**LEGEND**

- NOTES:**
1. NOT ALL COMPONENTS FOR TRAFFIC SIGNAL OPERATIONS ARE SHOWN. REFER TO TRAFFIC SIGNAL PLANS AND INTERCONNECT SHEETS FOR ADDITIONAL INFORMATION.



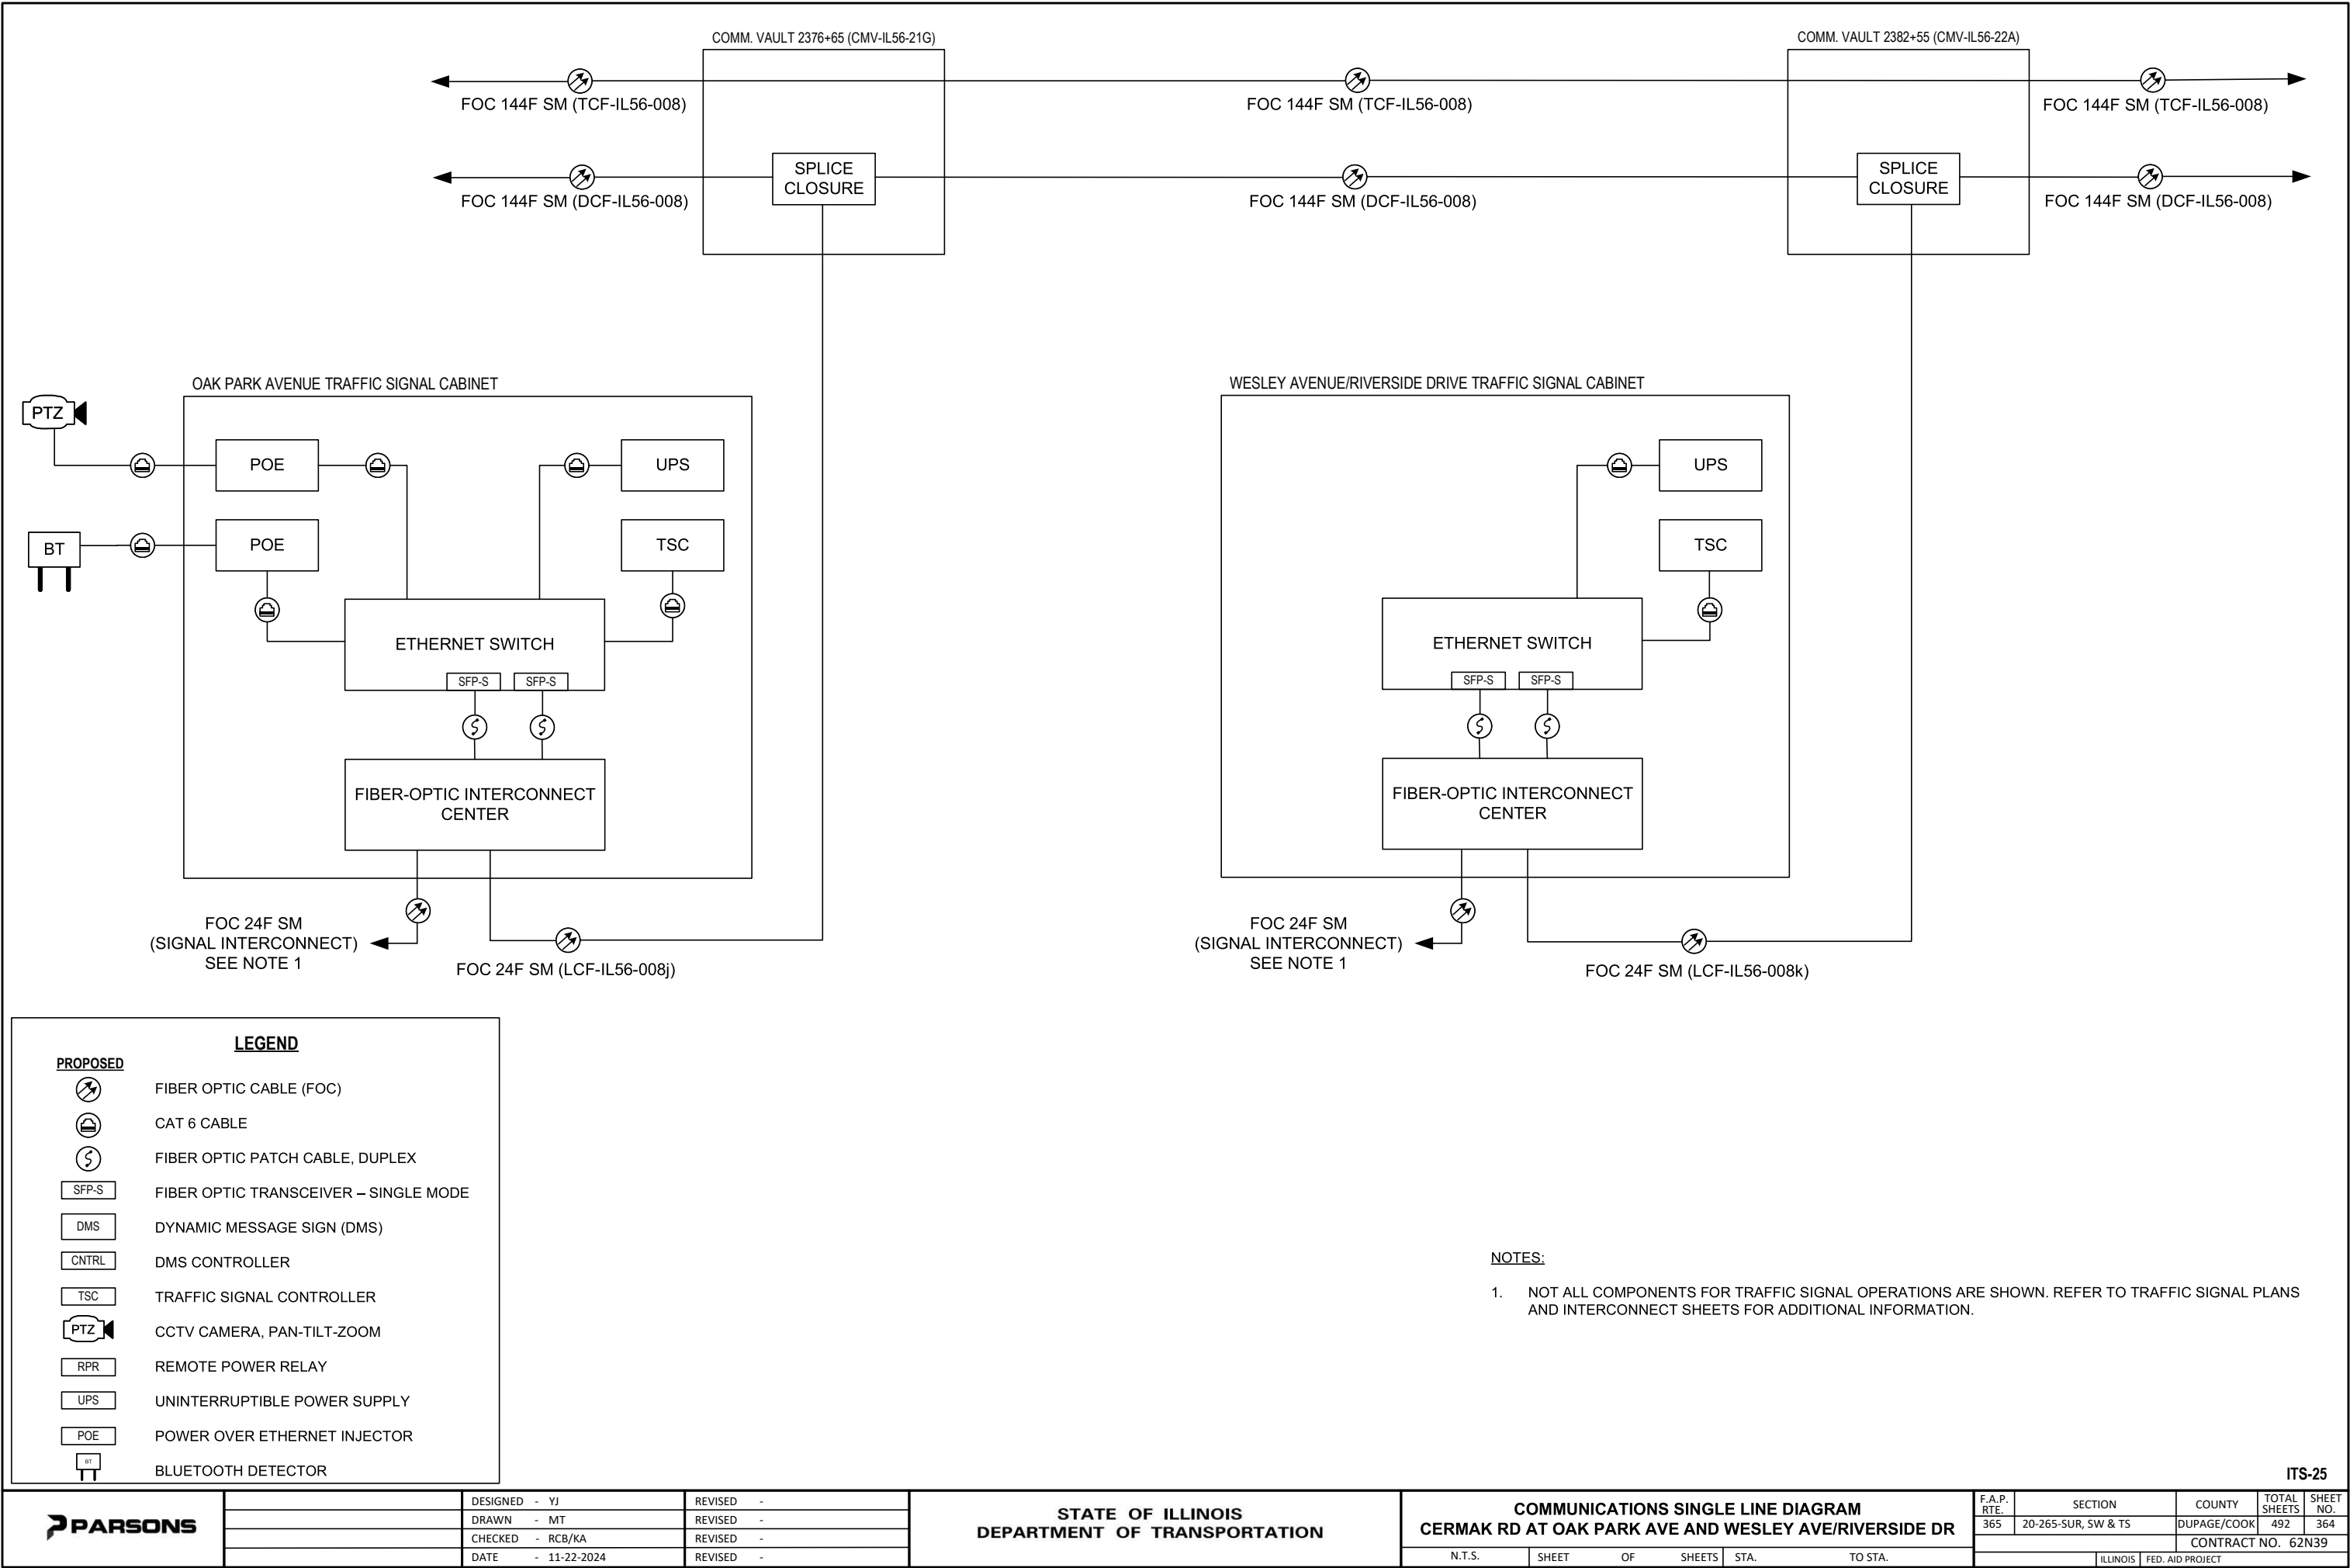

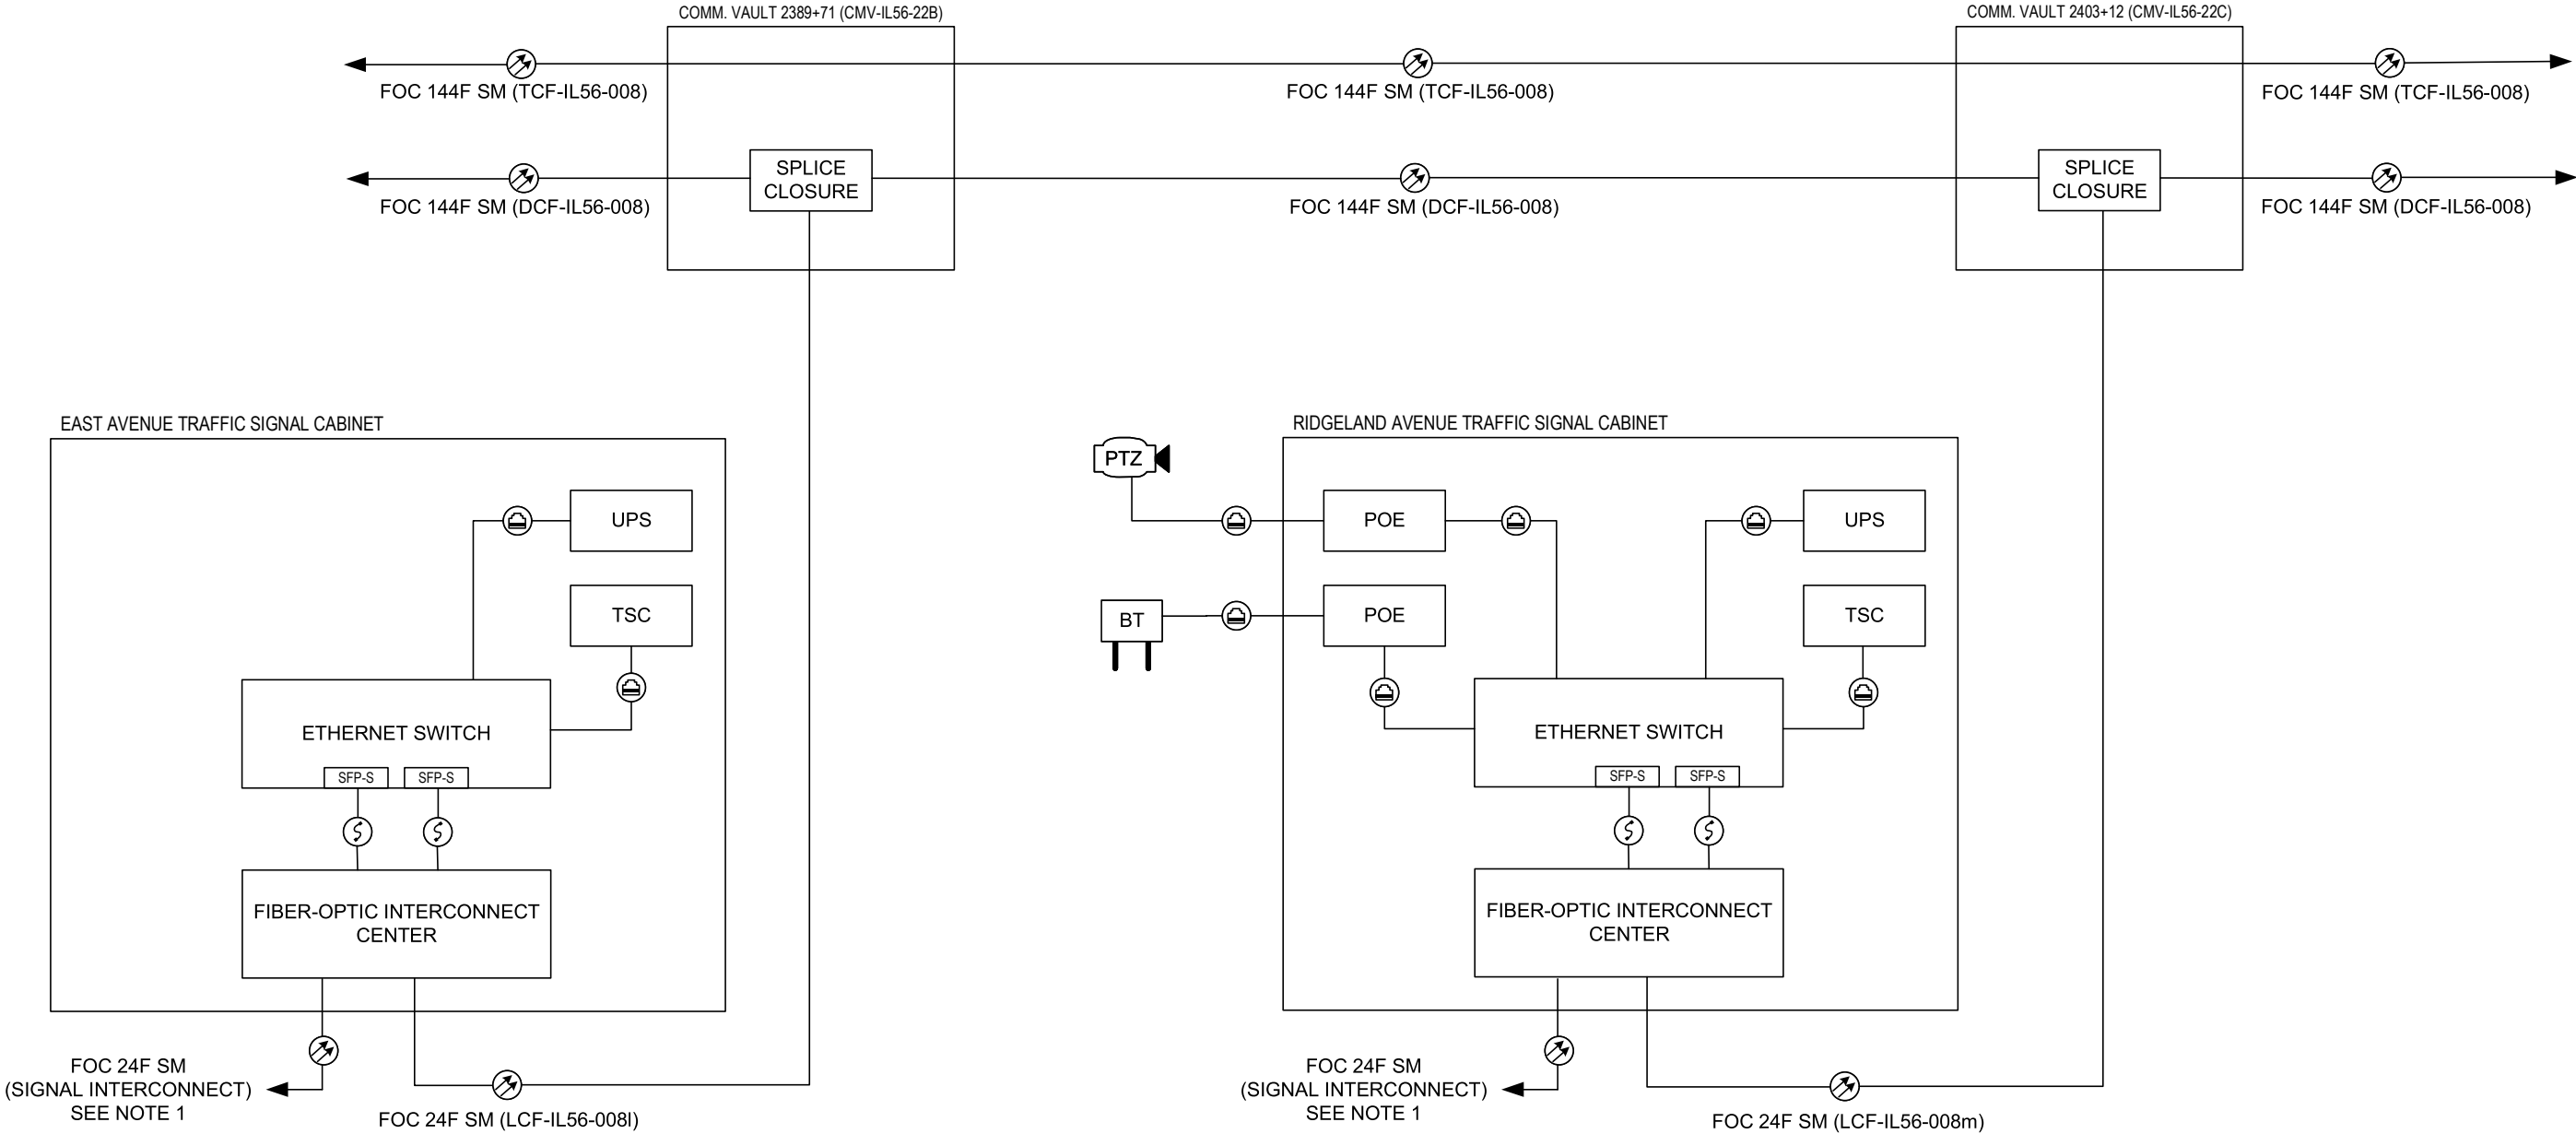

PROPOSED

FIBER OPTIC CABLE (FOC)

CAT 6 CABLE

FIBER OPTIC PATCH CABLE, DUPLEX

FIBER OPTIC TRANSCEIVER – SINGLE MODE

DYNAMIC MESSAGE SIGN (DMS)

DMS CONTROLLER

TRAFFIC SIGNAL CONTROLLER

CCTV CAMERA, PAN-TILT-ZOOM


REMOTE POWER RELAY

UNINTERRUPTIBLE POWER SUPPLY

POWER OVER ETHERNET INJECTOR

BLUETOOTH DETECTOR

- NOTES:
- NOT ALL COMPONENTS FOR TRAFFIC SIGNAL OPERATIONS ARE SHOWN. REFER TO TRAFFIC SIGNAL PLANS AND INTERCONNECT SHEETS FOR ADDITIONAL INFORMATION.

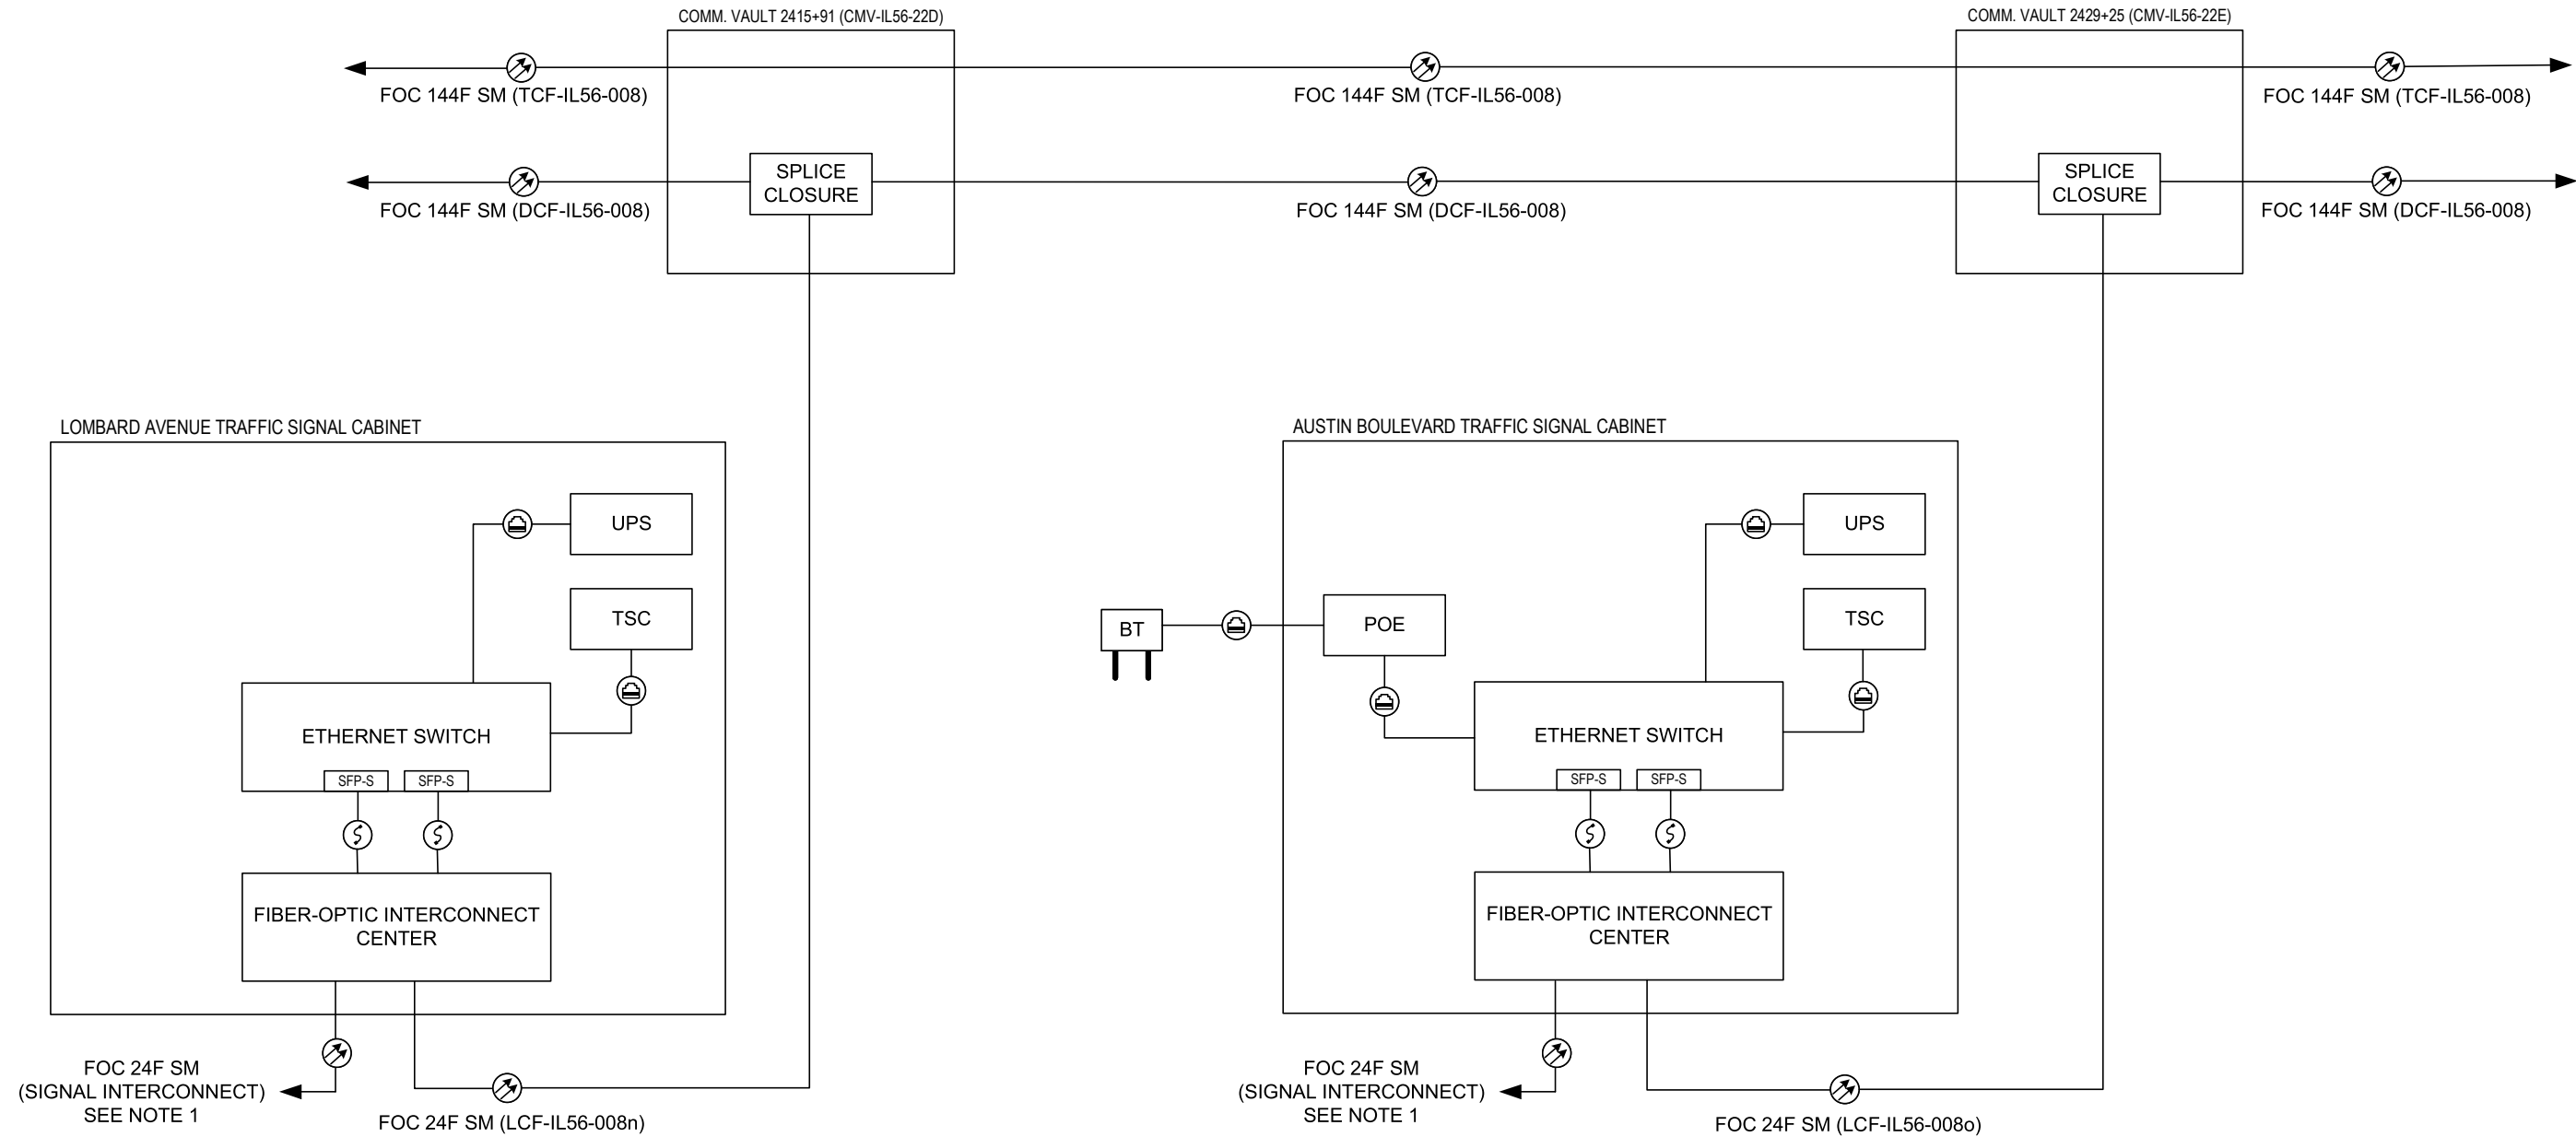

**PROPOSED**

**LEGEND**

FIBER OPTIC CABLE (FOC)

CAT 6 CABLE

FIBER OPTIC PATCH CABLE, DUPLEX

FIBER OPTIC TRANSCEIVER – SINGLE MODE

DYNAMIC MESSAGE SIGN (DMS)

DMS CONTROLLER

TRAFFIC SIGNAL CONTROLLER

CCTV CAMERA, PAN-TILT-ZOOM

REMOTE POWER RELAY

UNINTERRUPTIBLE POWER SUPPLY

POWER OVER ETHERNET INJECTOR

BLUETOOTH DETECTOR

- NOTES:**
1. NOT ALL COMPONENTS FOR TRAFFIC SIGNAL OPERATIONS ARE SHOWN. REFER TO TRAFFIC SIGNAL PLANS AND INTERCONNECT SHEETS FOR ADDITIONAL INFORMATION.



|          |   |            |
|----------|---|------------|
| DESIGNED | - | YJ         |
| DRAWN    | - | MT         |
| CHECKED  | - | RCB/KA     |
| DATE     | - | 11-22-2024 |


|         |   |
|---------|---|
| REVISED | - |
| REVISED | - |
| REVISED | - |
| REVISED | - |


STATE OF ILLINOIS  
DEPARTMENT OF TRANSPORTATION

COMMUNICATIONS SINGLE LINE DIAGRAM  
CERMAK RD AT LOMBARD AVENUE AND AUSTIN BOULEVARD

|        |       |    |        |      |         |
|--------|-------|----|--------|------|---------|
| N.T.S. | SHEET | OF | SHEETS | STA. | TO STA. |
|--------|-------|----|--------|------|---------|

| F.A.P. RTE.               | SECTION             | COUNTY      | TOTAL SHEETS | SHEET NO. |
|---------------------------|---------------------|-------------|--------------|-----------|
| 365                       | 20-265-SUR, SW & TS | DUPAGE/COOK | 492          | 366       |
| CONTRACT NO. 62N39        |                     |             |              |           |
| ILLINOIS FED. AID PROJECT |                     |             |              |           |

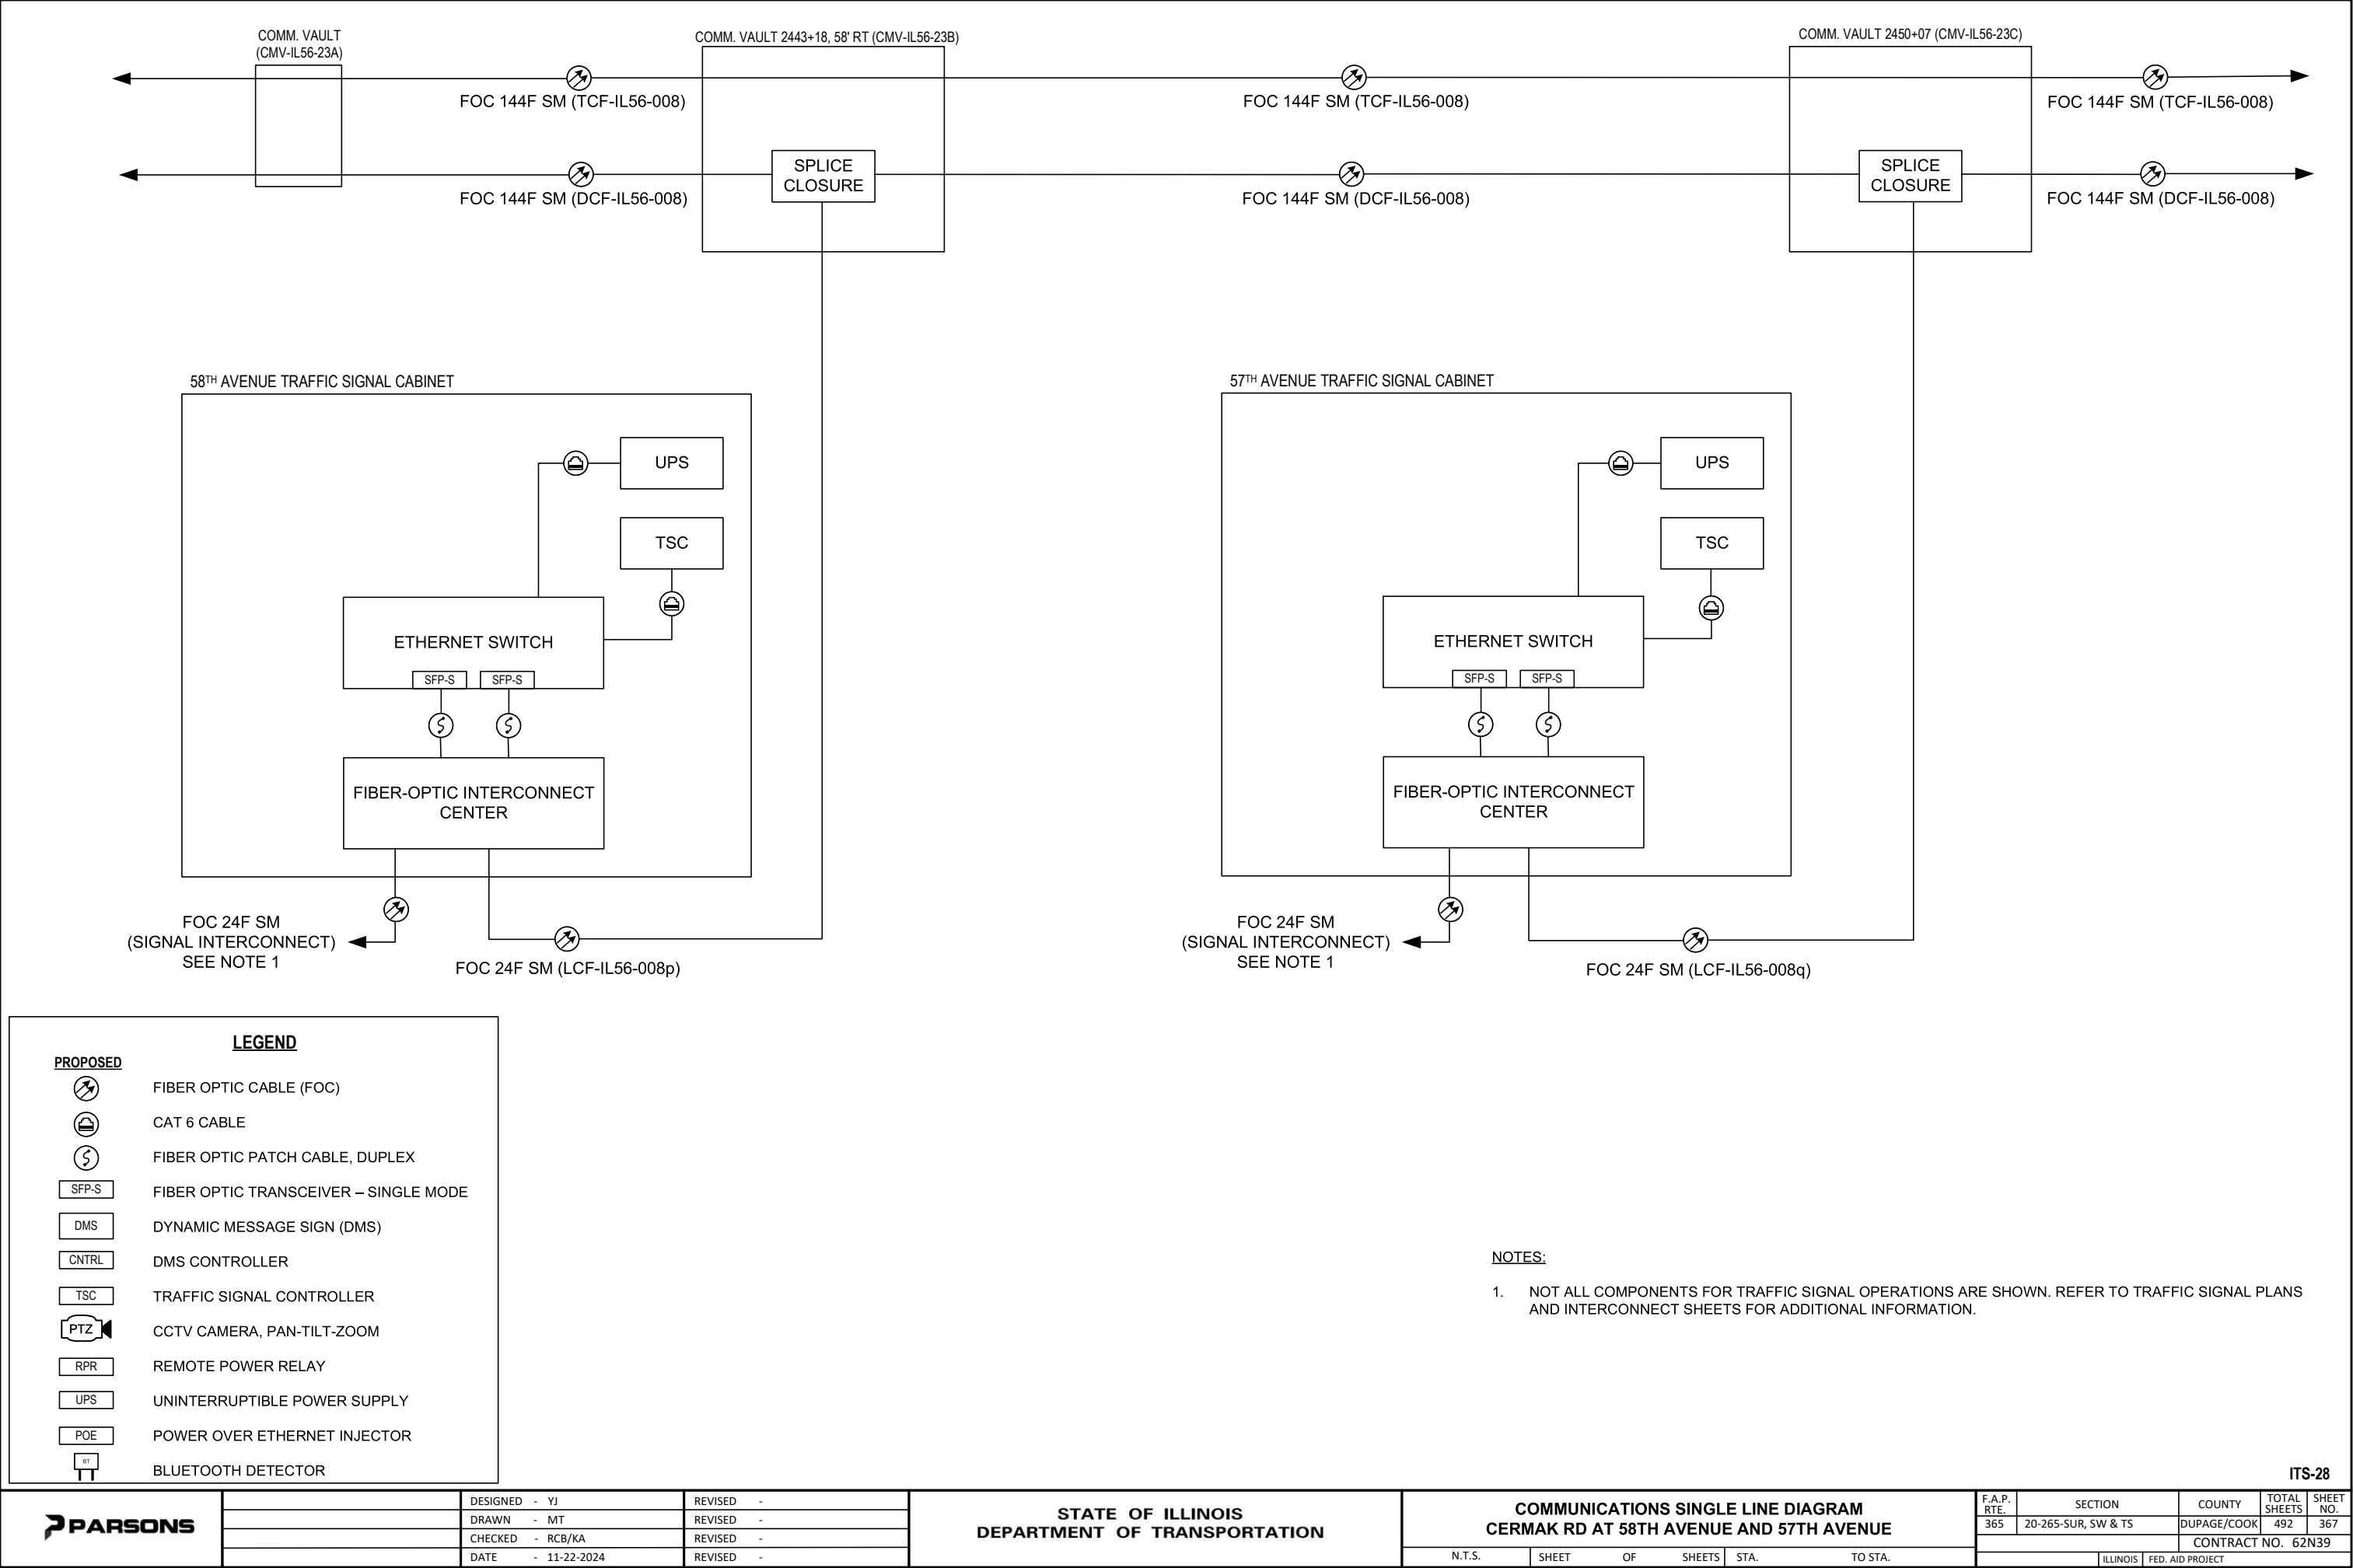

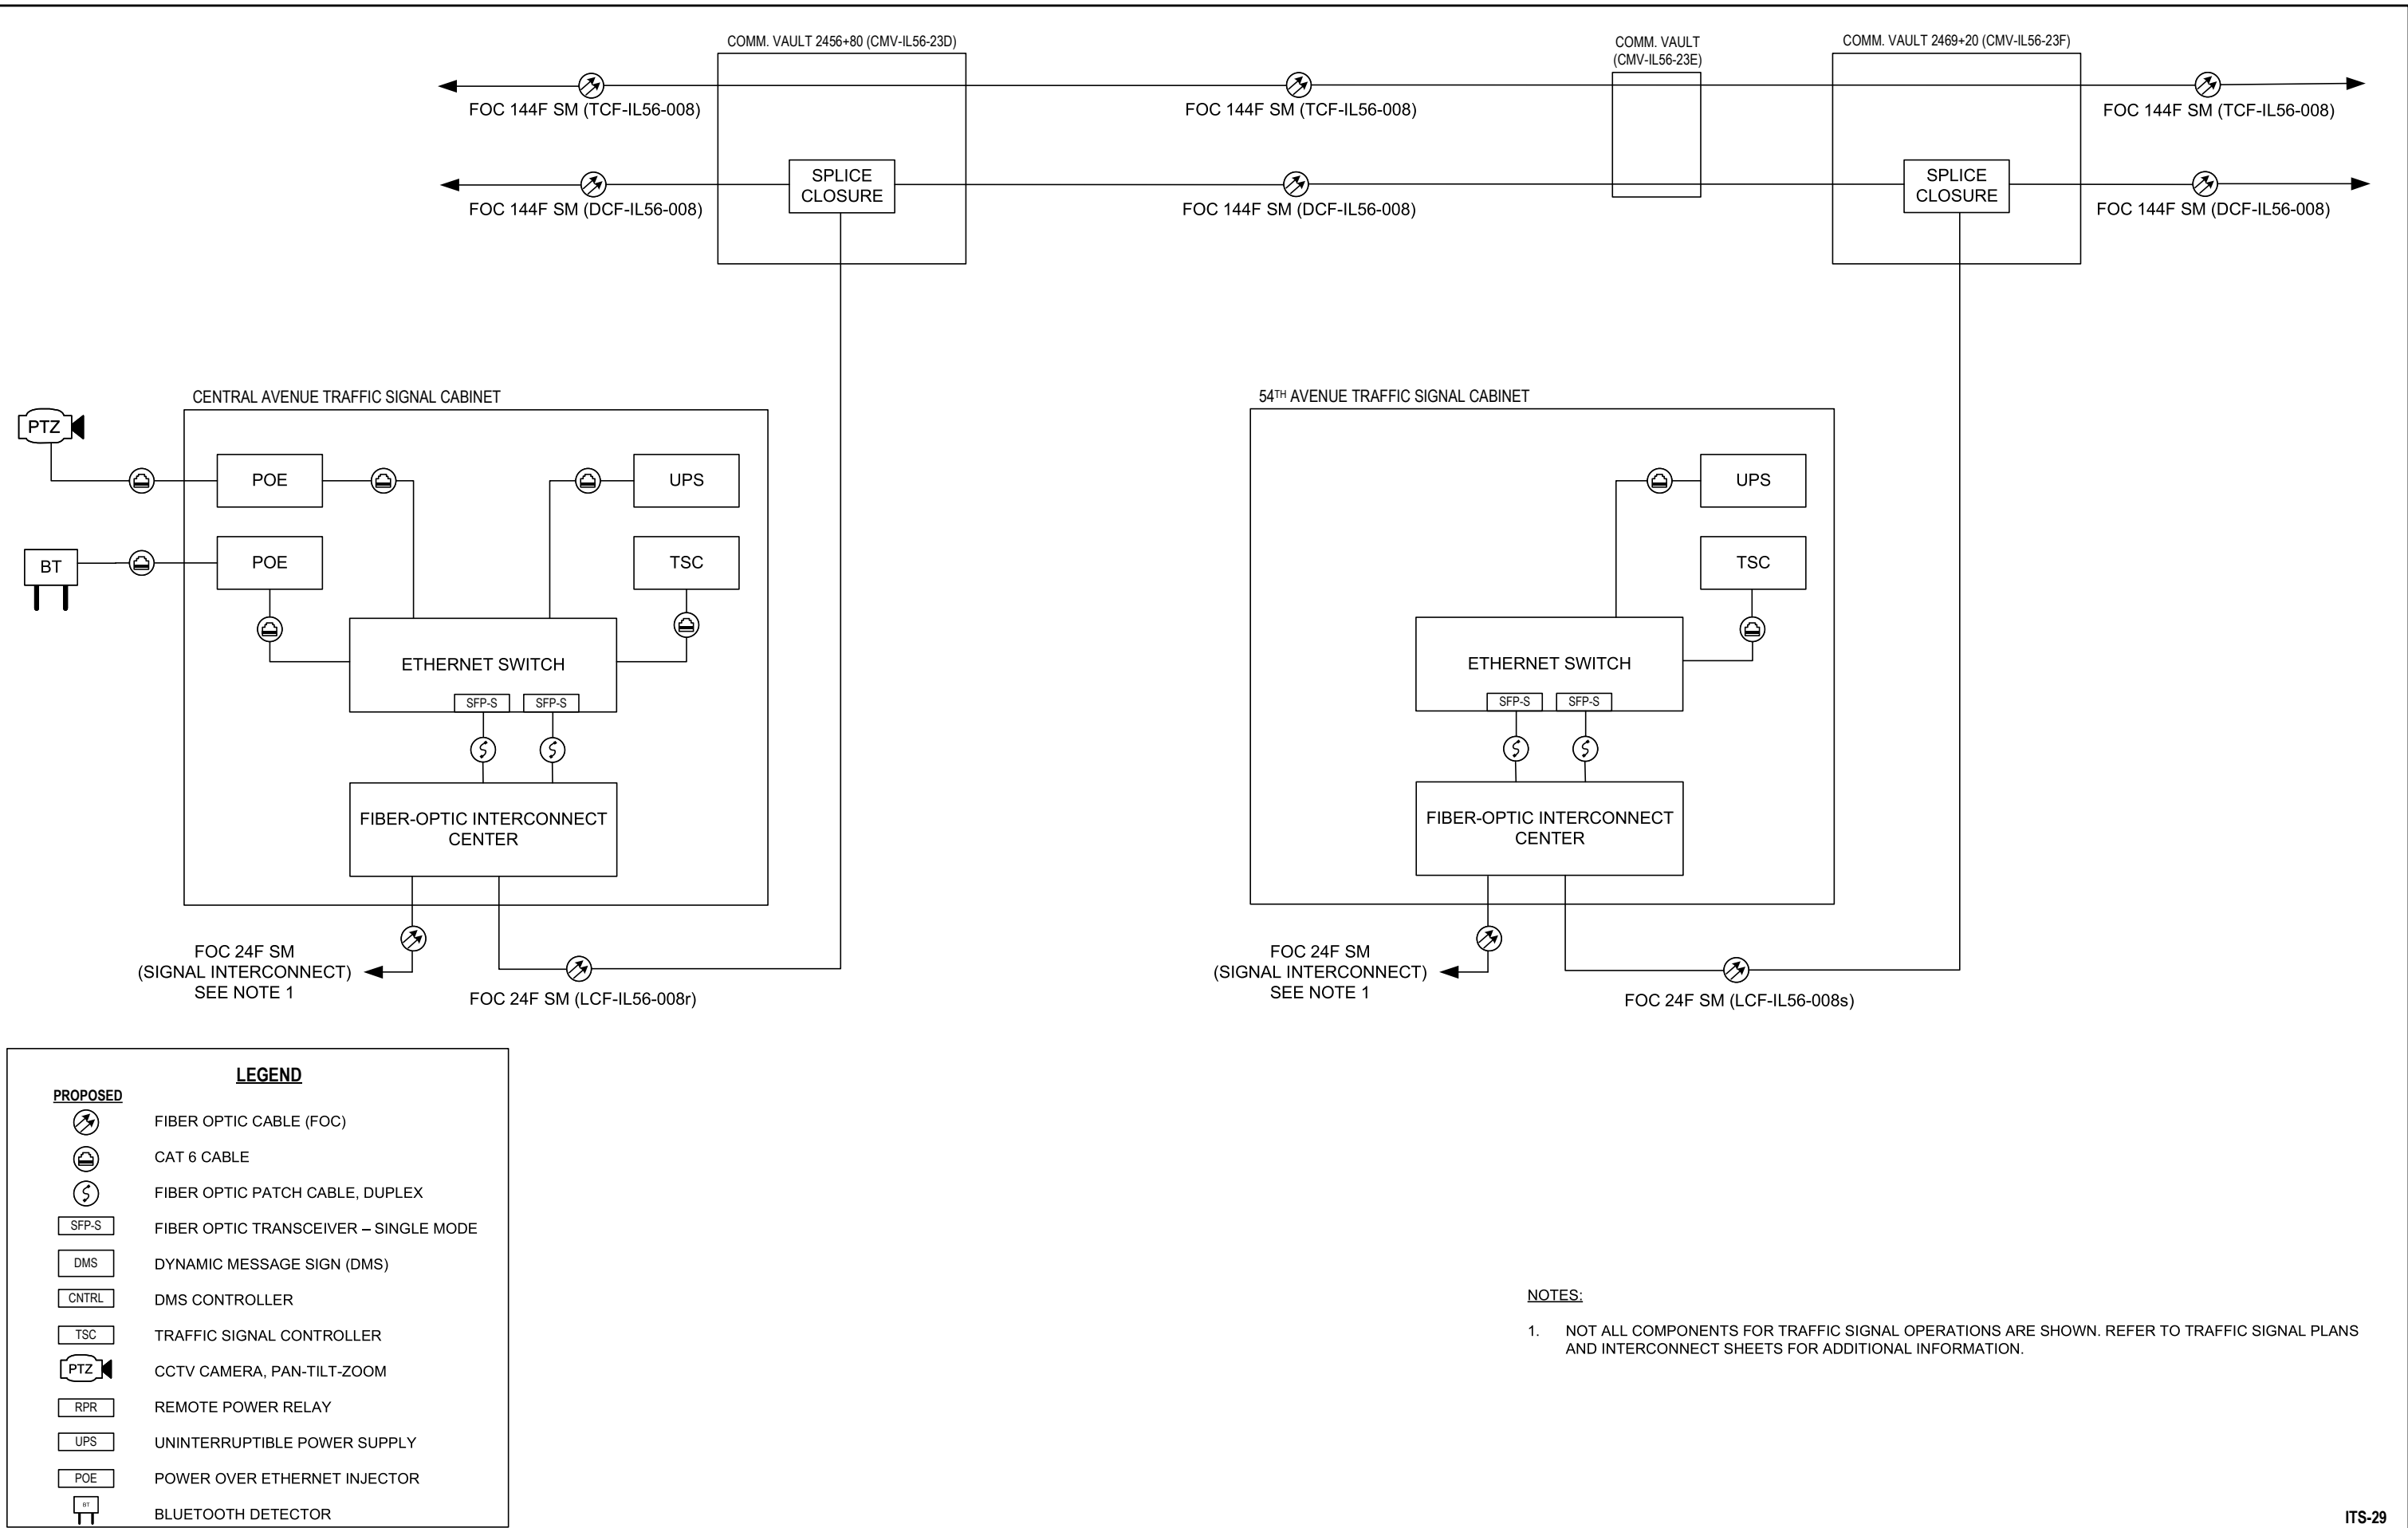

**PROPOSED**

FIBER OPTIC CABLE (FOC)

CAT 6 CABLE

FIBER OPTIC PATCH CABLE, DUPLEX

FIBER OPTIC TRANSCEIVER – SINGLE MODE

DYNAMIC MESSAGE SIGN (DMS)

DMS CONTROLLER

TRAFFIC SIGNAL CONTROLLER

CCTV CAMERA, PAN-TILT-ZOOM

REMOTE POWER RELAY

UNINTERRUPTIBLE POWER SUPPLY

POWER OVER ETHERNET INJECTOR

BLUETOOTH DETECTOR

**LEGEND**

- NOTES:**
- NOT ALL COMPONENTS FOR TRAFFIC SIGNAL OPERATIONS ARE SHOWN. REFER TO TRAFFIC SIGNAL PLANS AND INTERCONNECT SHEETS FOR ADDITIONAL INFORMATION.



|          |   |            |
|----------|---|------------|
| DESIGNED | - | YJ         |
| DRAWN    | - | MT         |
| CHECKED  | - | RCB/KA     |
| DATE     | - | 11-22-2024 |


|         |   |
|---------|---|
| REVISED | - |
| REVISED | - |
| REVISED | - |
| REVISED | - |

STATE OF ILLINOIS  
DEPARTMENT OF TRANSPORTATION


COMMUNICATIONS SINGLE LINE DIAGRAM  
CERMAK RD AT CENTRAL AVENUE AND 54TH AVENUE

|        |       |    |        |      |         |
|--------|-------|----|--------|------|---------|
| N.T.S. | SHEET | OF | SHEETS | STA. | TO STA. |
|--------|-------|----|--------|------|---------|

| F.A.P. RTE.               | SECTION             | COUNTY      | TOTAL SHEETS | SHEET NO. |
|---------------------------|---------------------|-------------|--------------|-----------|
| 365                       | 20-265-SUR, SW & TS | DUPAGE/COOK | 492          | 368       |
| CONTRACT NO. 62N39        |                     |             |              |           |
| ILLINOIS FED. AID PROJECT |                     |             |              |           |

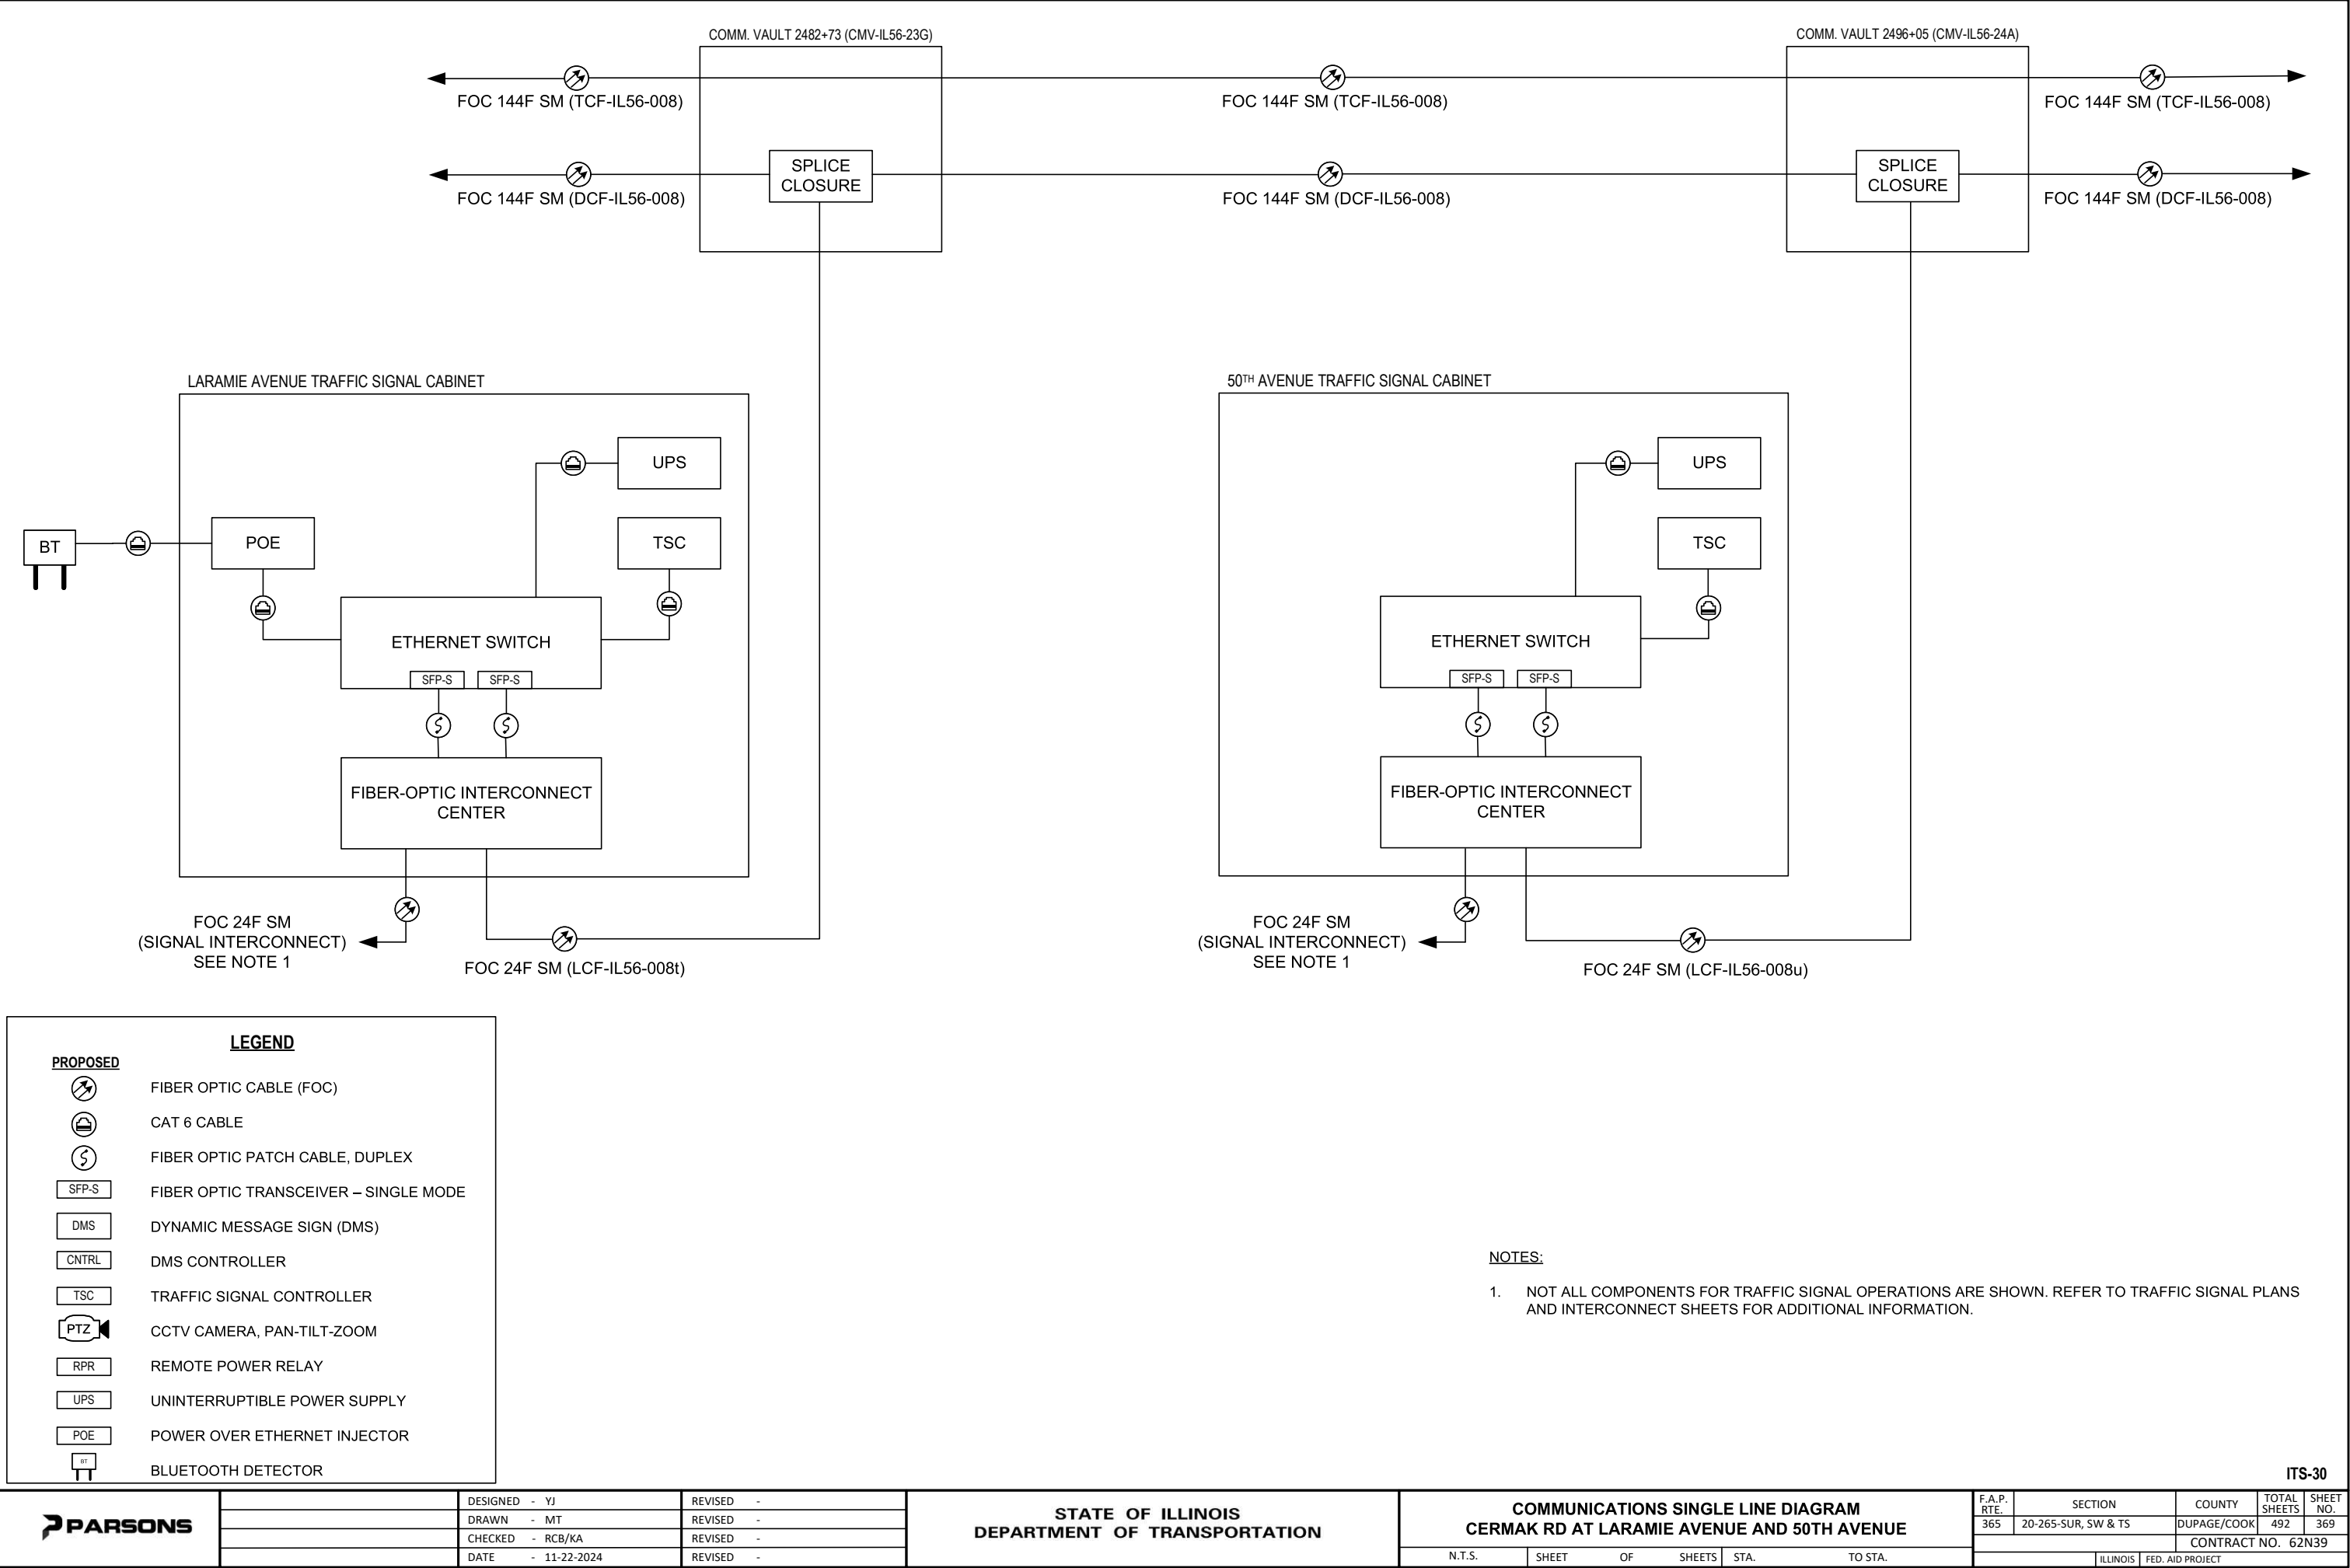



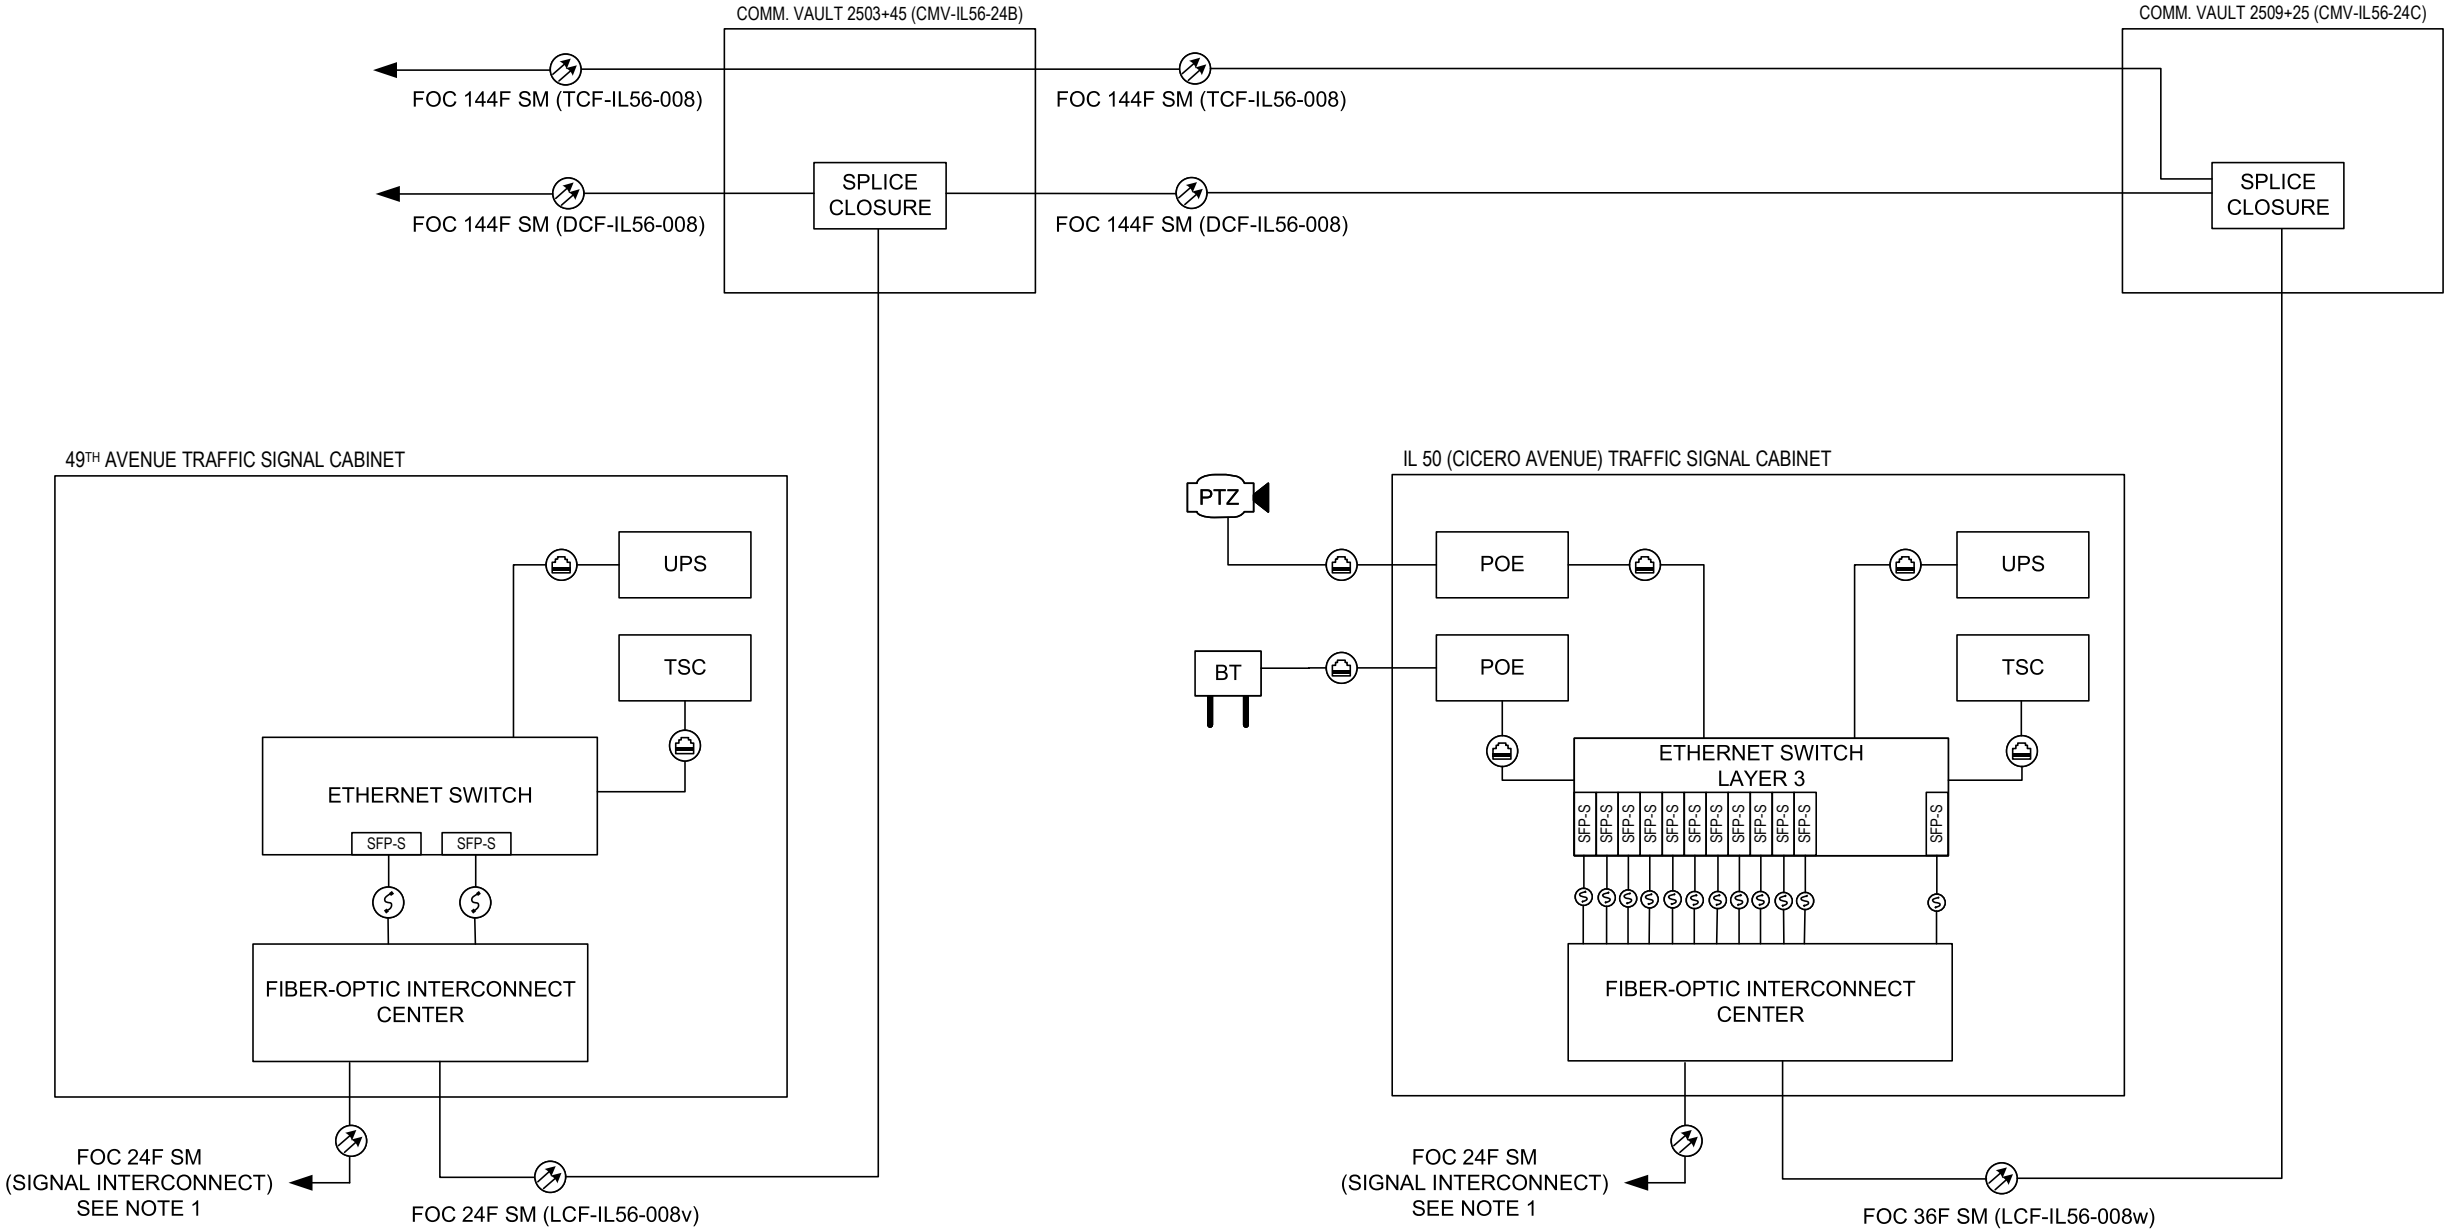

PROPOSED

FIBER OPTIC CABLE (FOC)

CAT 6 CABLE

FIBER OPTIC PATCH CABLE, DUPLEX

FIBER OPTIC TRANSCEIVER – SINGLE MODE

DYNAMIC MESSAGE SIGN (DMS)

DMS CONTROLLER

TRAFFIC SIGNAL CONTROLLER


CCTV CAMERA, PAN-TILT-ZOOM

REMOTE POWER RELAY


UNINTERRUPTIBLE POWER SUPPLY

POWER OVER ETHERNET INJECTOR

BLUETOOTH DETECTOR

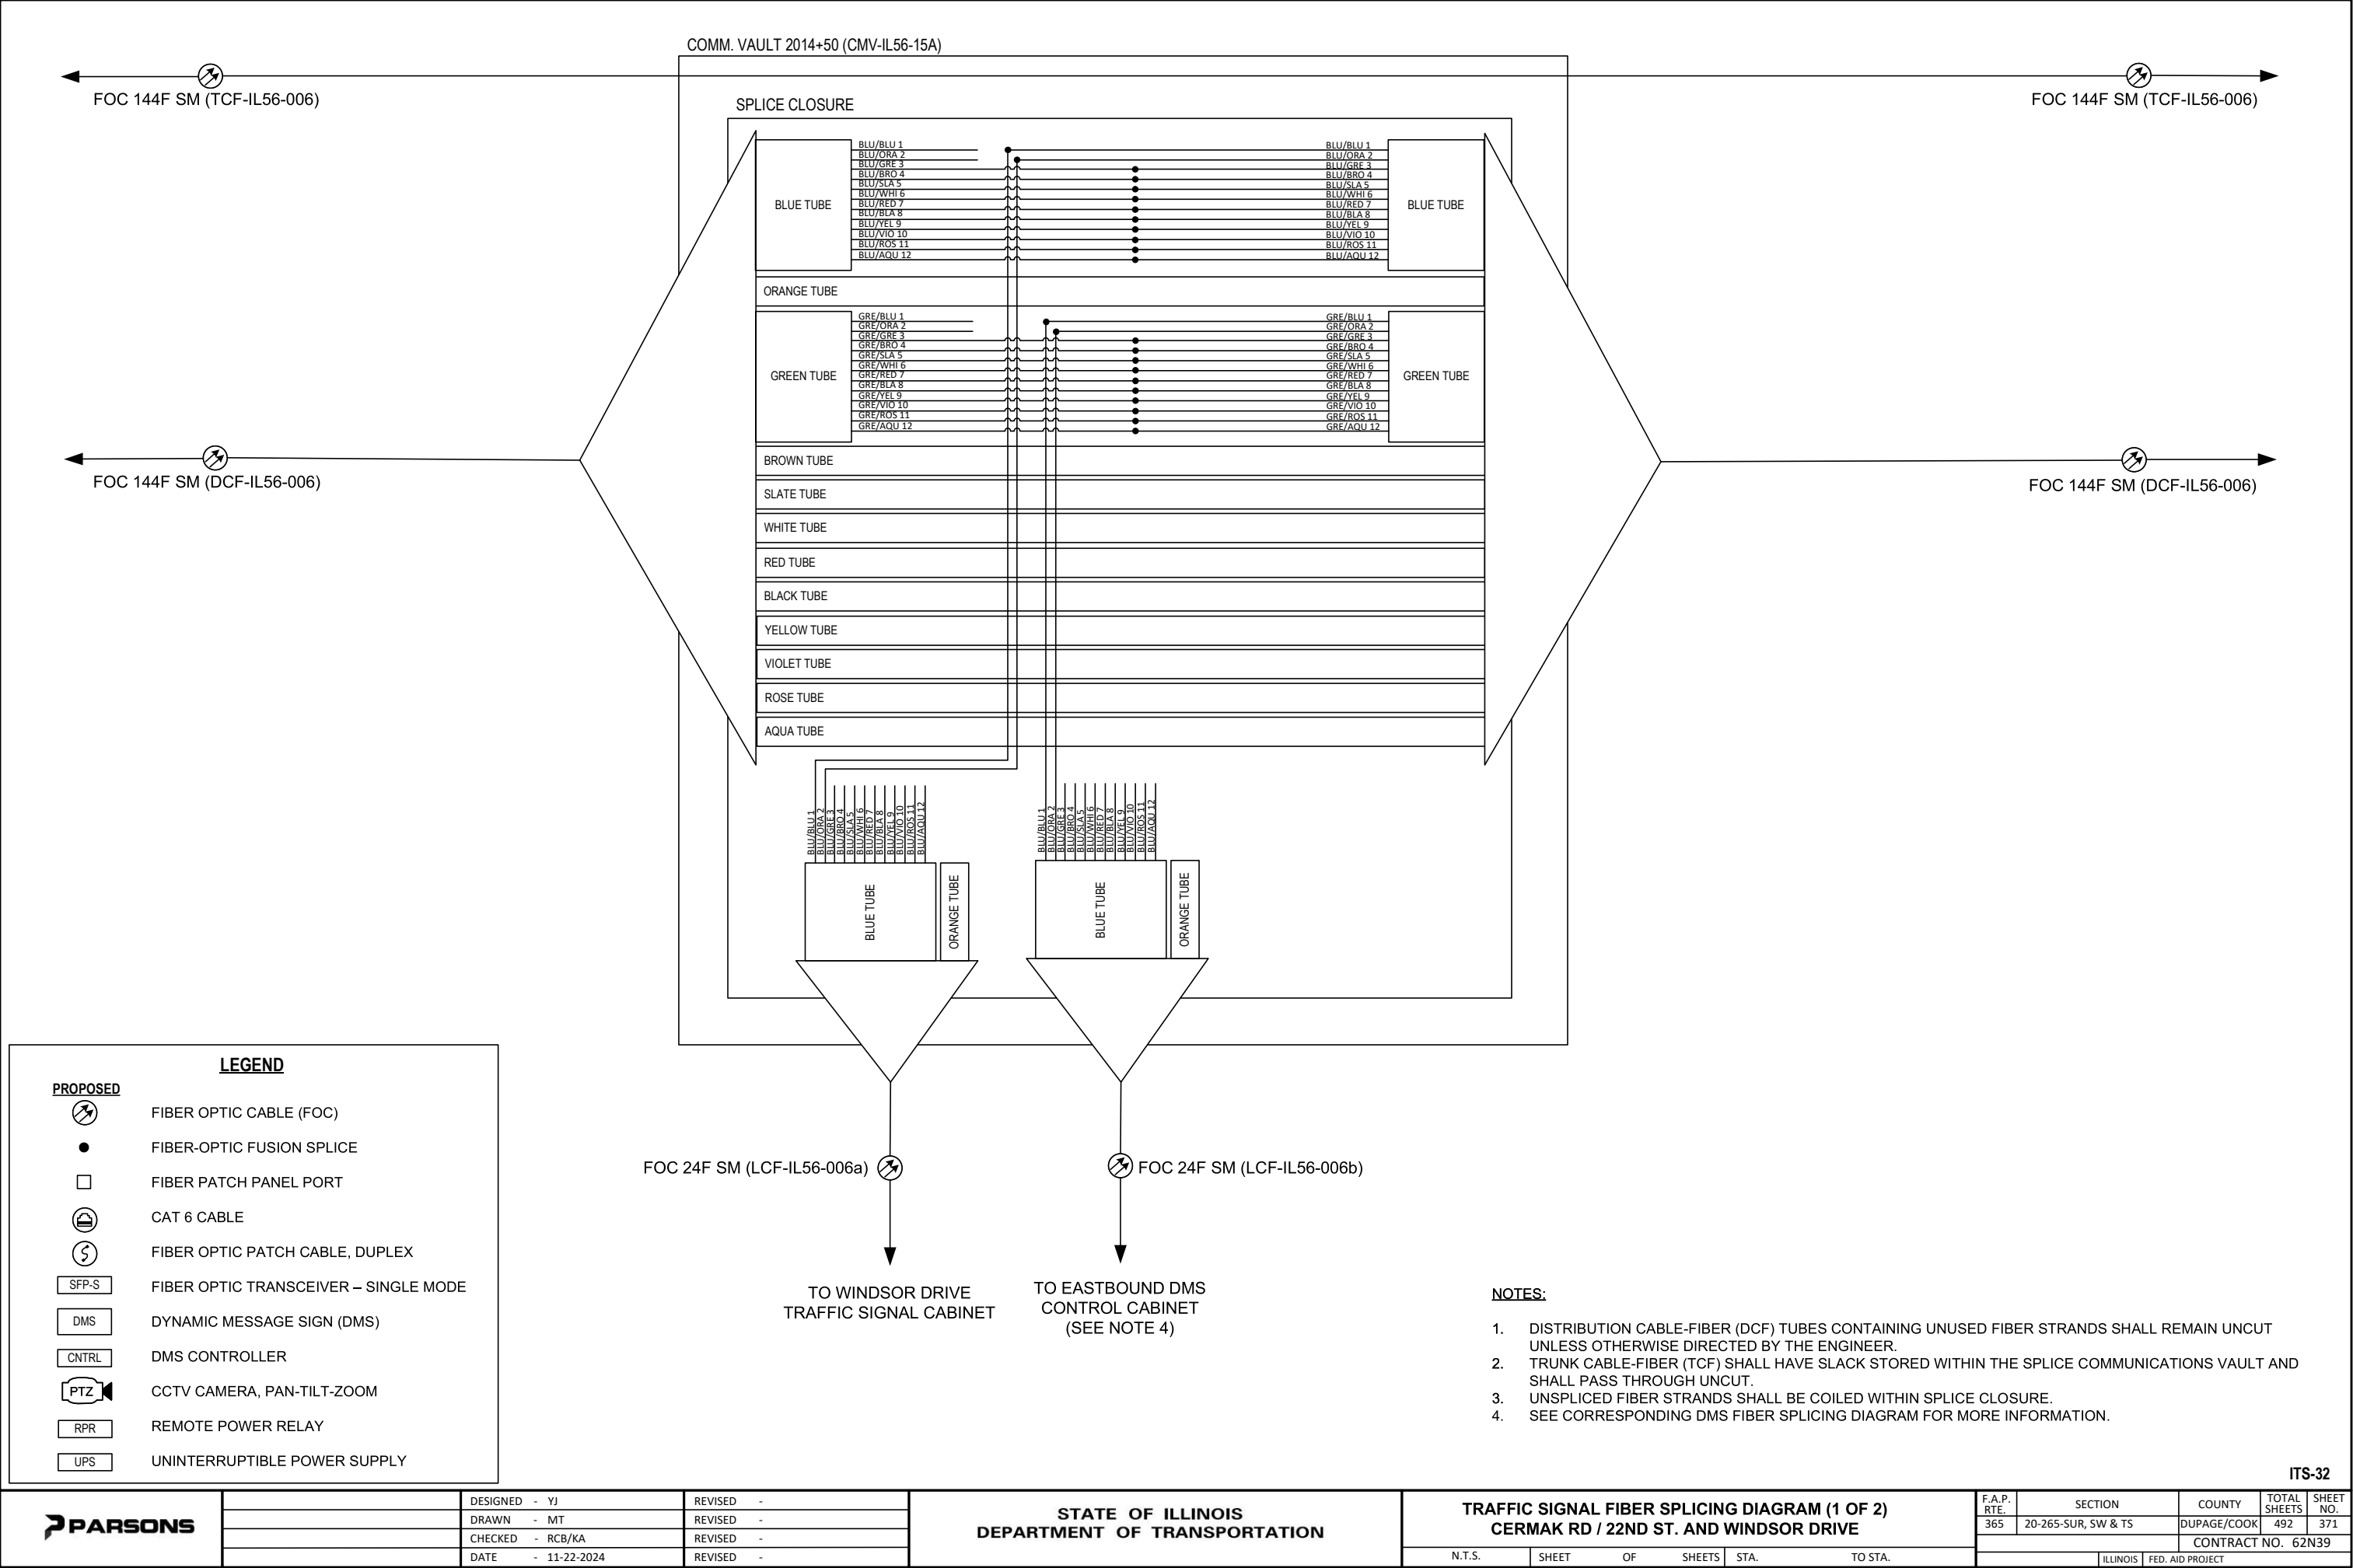



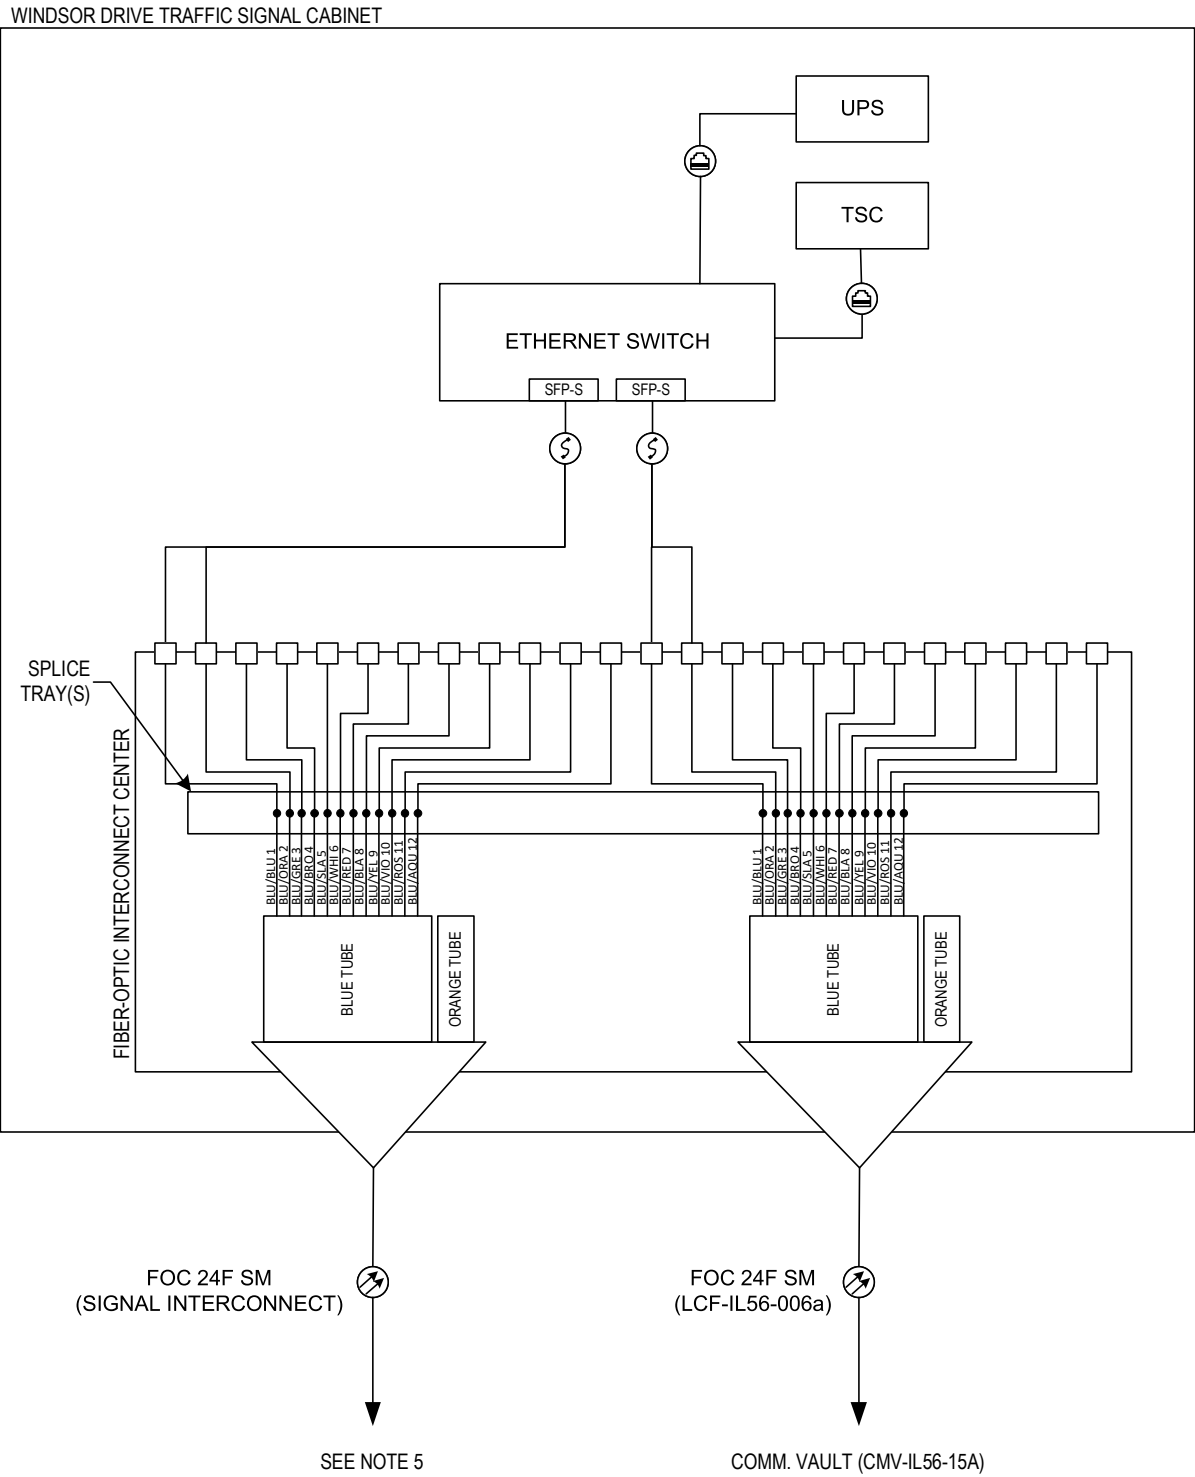




**LEGEND**

**PROPOSED**

- FIBER OPTIC CABLE (FOC)
- FIBER-OPTIC FUSION SPLICE
- FIBER PATCH PANEL PORT
- CAT 6 CABLE
- FIBER OPTIC PATCH CABLE, DUPLEX
- FIBER OPTIC TRANSCEIVER – SINGLE MODE
- BLUETOOTH DETECTOR
- TRAFFIC SIGNAL CONTROLLER
- CCTV CAMERA, PAN-TILT-ZOOM
- POWER OVER ETHERNET INJECTOR
- UNINTERRUPTIBLE POWER SUPPLY

- NOTES:**
- DISTRIBUTION CABLE-FIBER (DCF) TUBES CONTAINING UNUSED FIBER STRANDS SHALL REMAIN UNCUT UNLESS OTHERWISE DIRECTED BY THE ENGINEER.
  - TRUNK CABLE-FIBER (TCF) SHALL HAVE SLACK STORED WITHIN THE SPLICE COMMUNICATIONS VAULT AND SHALL PASS THROUGH UNCUT.
  - UNSPLICED FIBER STRANDS SHALL BE COILED WITHIN SPLICE TRAY.
  - FIBER-OPTIC CABLE DEPICTED IS GUIDANCE ONLY. ACTUAL FIBER-OPTIC CABLE FROM DMS CONTROLLER TO DMS DISPLAY SHALL BE IN ACCORDANCE WITH THE DMS MANUFACTURER'S REQUIREMENTS.
  - REFER TO TRAFFIC SIGNAL PLANS AND INTERCONNECT SHEETS FOR ADDITIONAL INFORMATION.

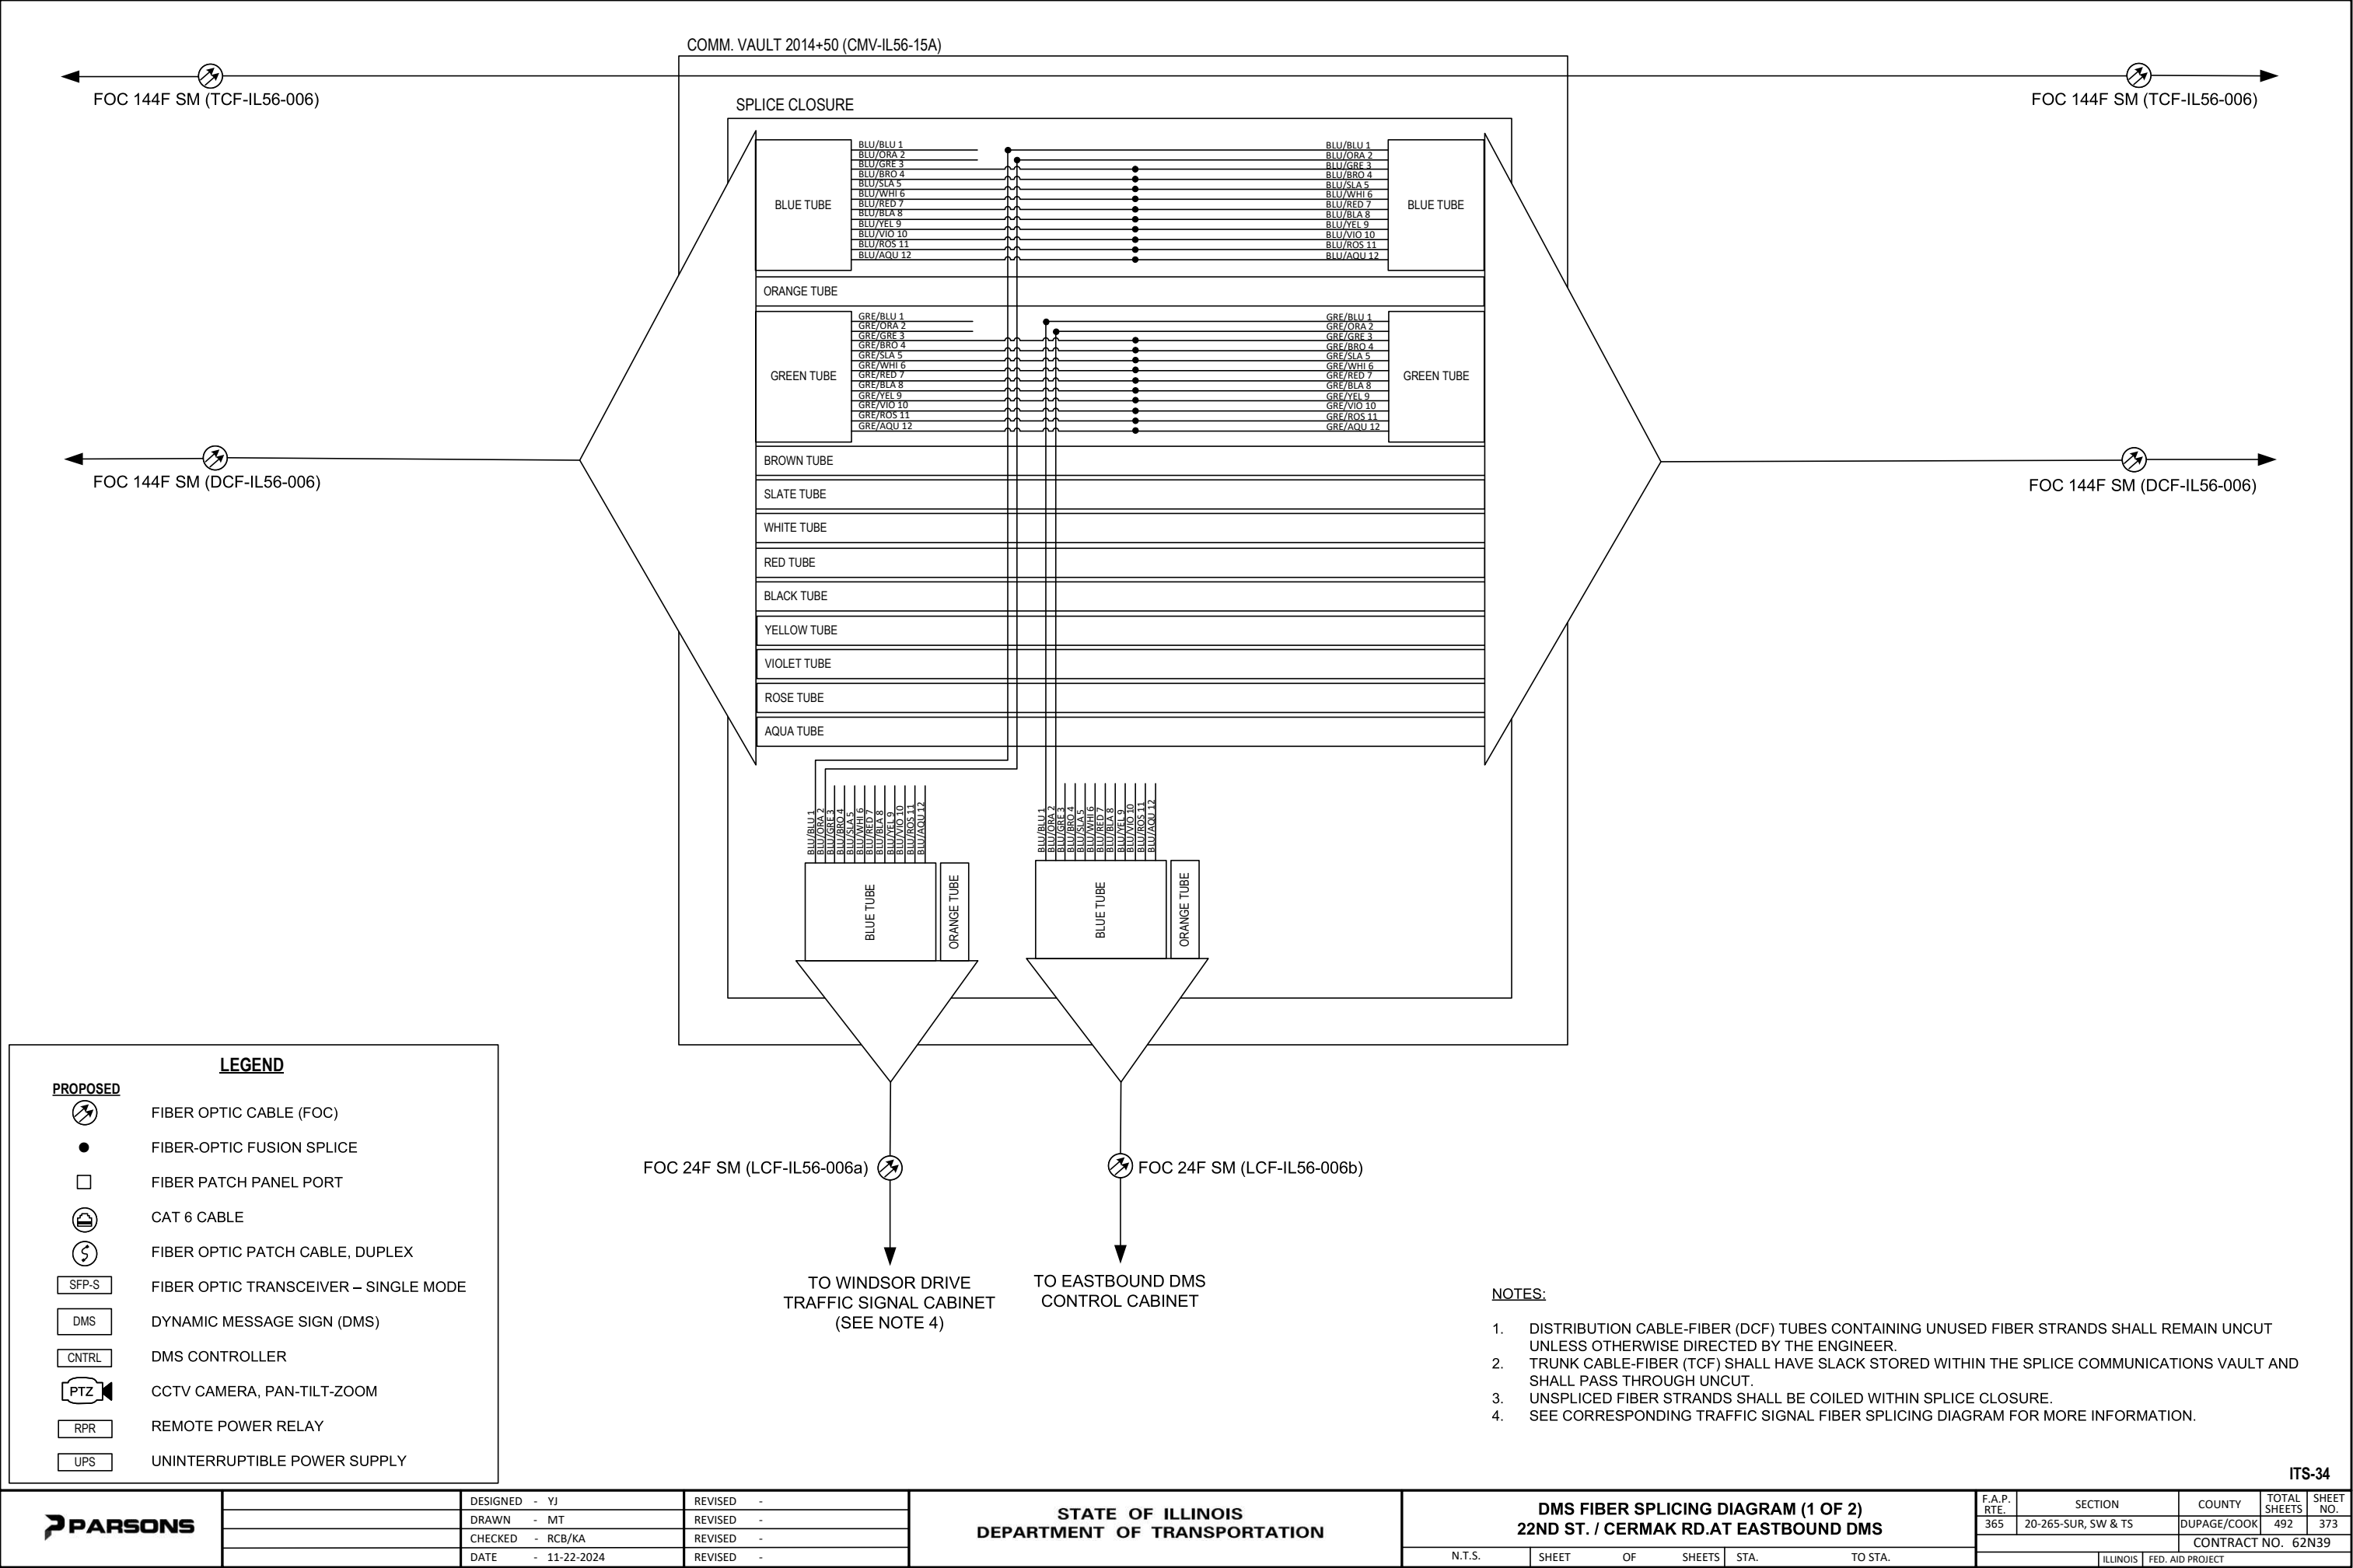

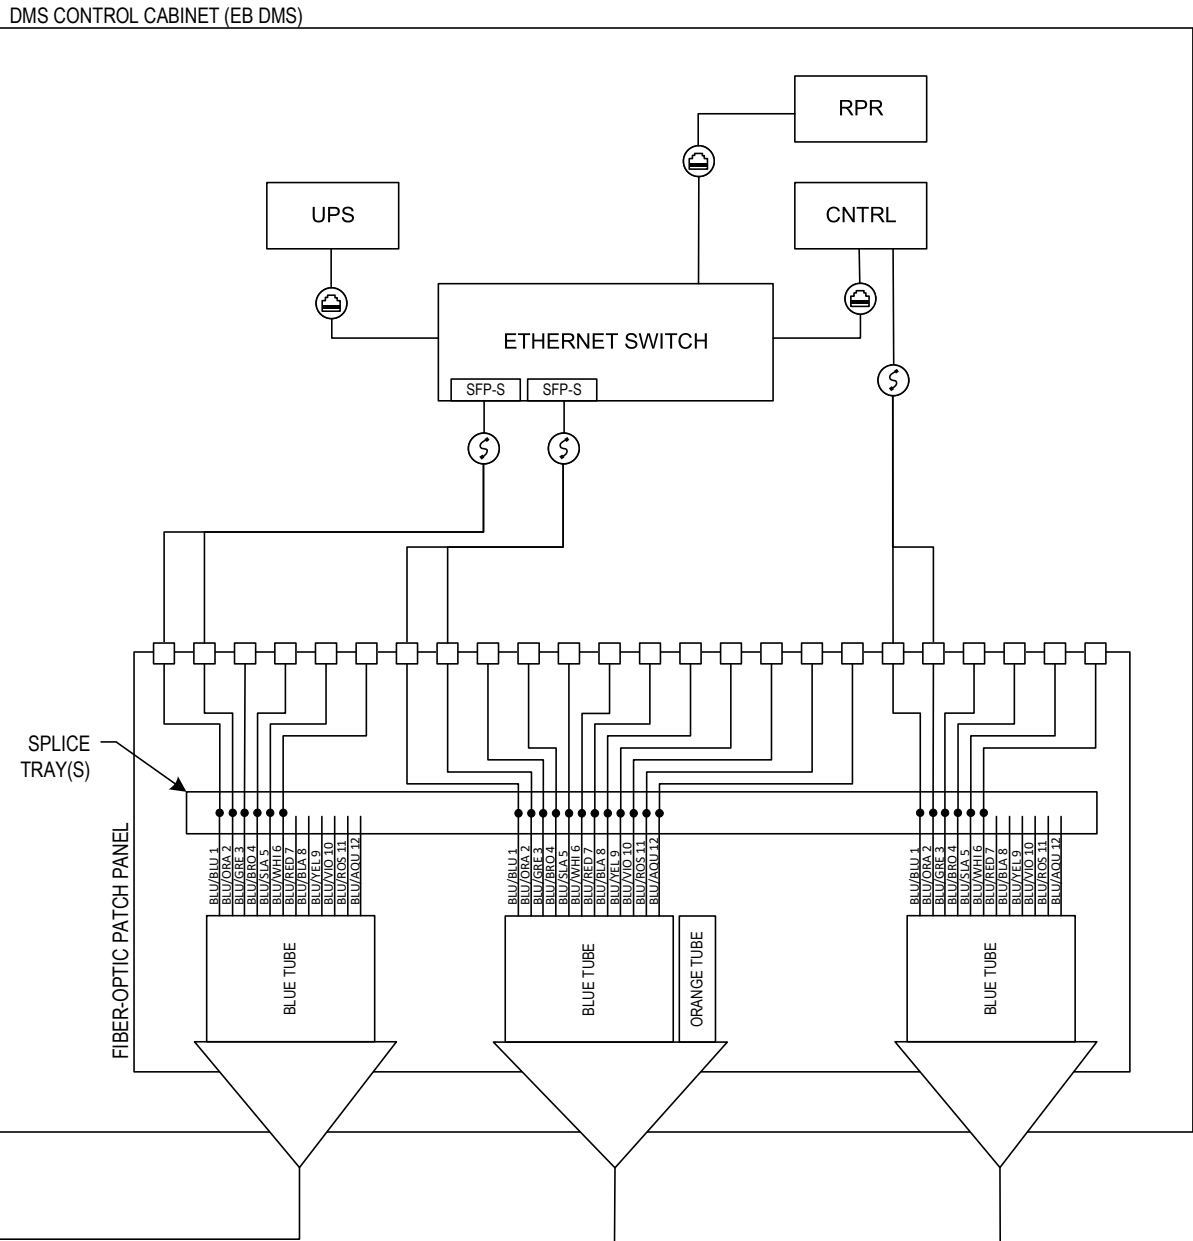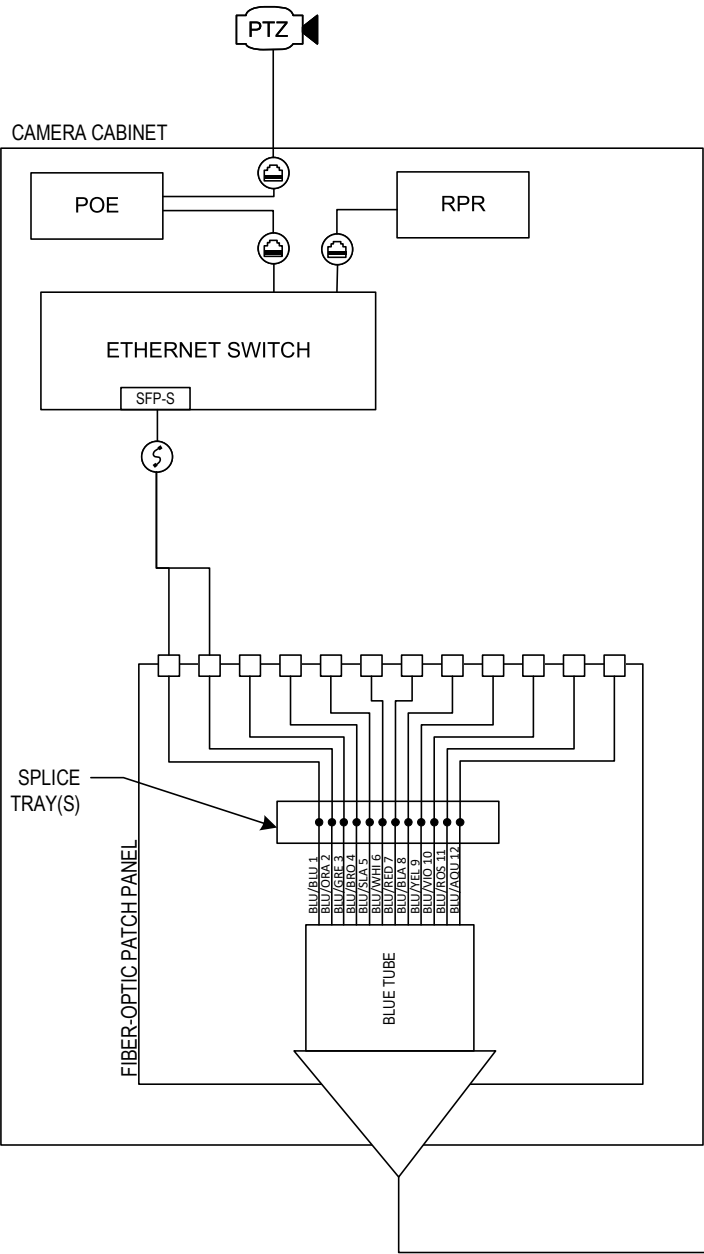

FOC 12F SM

FOC 24F SM (LCF-IL56-006b)

FOC PER DMS MANUFACTURER (SEE NOTE 4)

TO COMM. VAULT 2014+50 (CMV-IL56-15A)

TO DMS DISPLAY

- NOTES:
- 1. DISTRIBUTION CABLE-FIBER (DCF) TUBES CONTAINING UNUSED FIBER STRANDS SHALL REMAIN UNCUT UNLESS OTHERWISE DIRECTED BY THE ENGINEER.
  - 2. TRUNK CABLE-FIBER (TCF) SHALL HAVE SLACK STORED WITHIN THE SPLICE COMMUNICATIONS VAULT AND SHALL PASS THROUGH UNCUT.
  - 3. UNSPLICED FIBER STRANDS SHALL BE COILED WITHIN SPLICE TRAY.
  - 4. FIBER-OPTIC CABLE DEPICTED IS GUIDANCE ONLY. ACTUAL FIBER-OPTIC CABLE FROM DMS CONTROLLER TO DMS DISPLAY SHALL BE IN ACCORDANCE WITH THE DMS MANUFACTURER'S REQUIREMENTS.

LEGEND

PROPOSED

FIBER OPTIC CABLE (FOC)

FIBER-OPTIC FUSION SPLICE

FIBER PATCH PANEL PORT

CAT 6 CABLE

FIBER OPTIC PATCH CABLE, DUPLEX

FIBER OPTIC TRANSCEIVER – SINGLE MODE

DYNAMIC MESSAGE SIGN (DMS)


DMS CONTROLLER


CCTV CAMERA, PAN-TILT-ZOOM

REMOTE POWER RELAY

UNINTERRUPTIBLE POWER SUPPLY

ITS-35

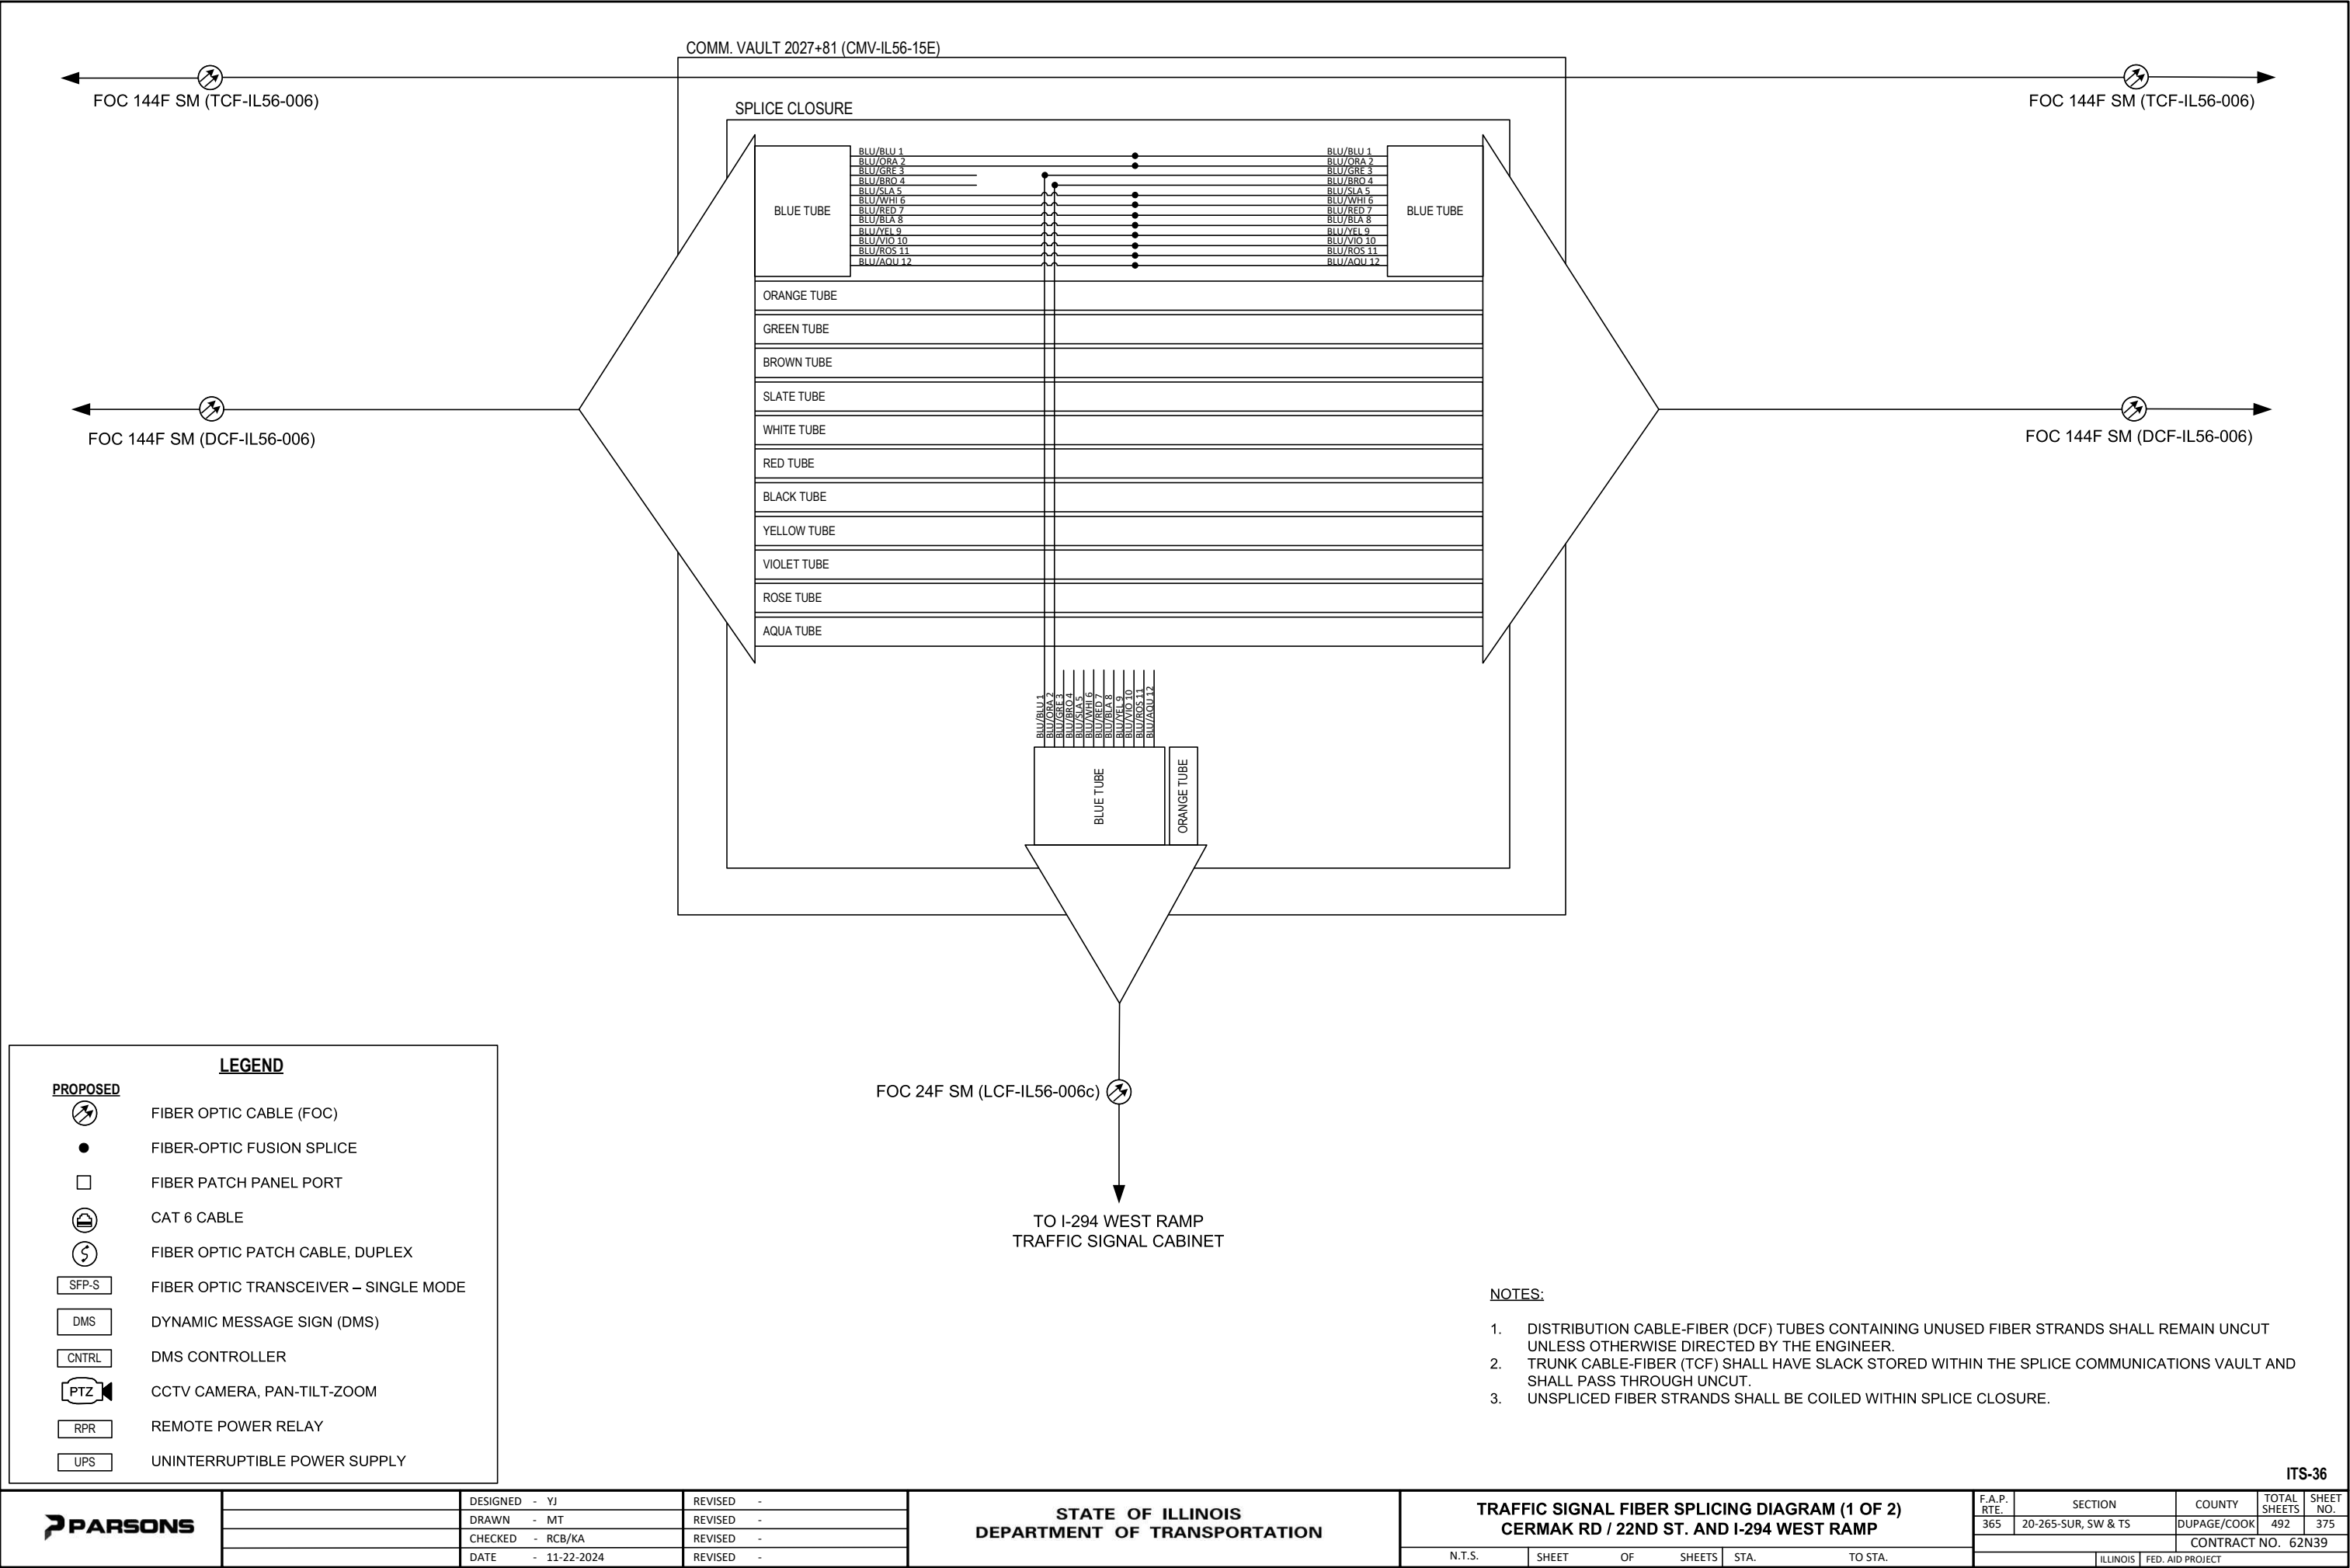

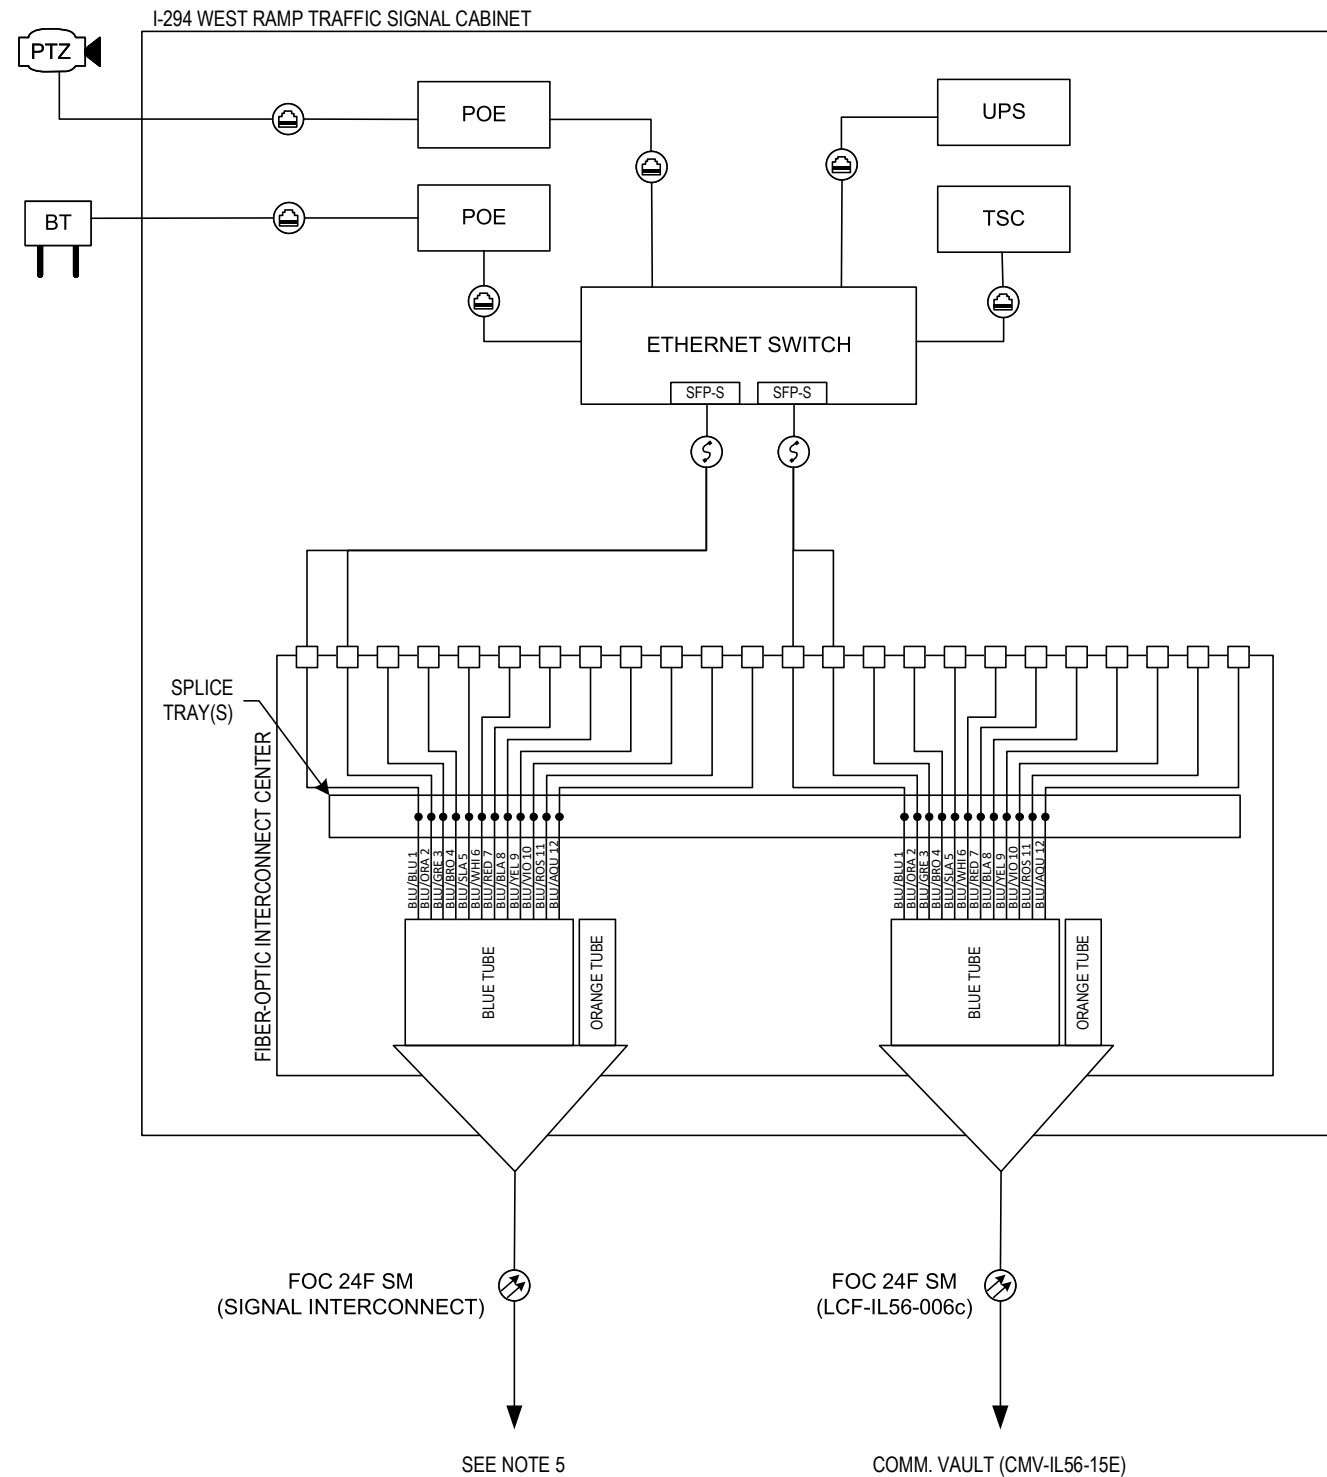

### LEGEND

#### PROPOSED

-  FIBER OPTIC CABLE (FOC)
-  FIBER-OPTIC FUSION SPLICE
-  FIBER PATCH PANEL PORT
-  CAT 6 CABLE
-  FIBER OPTIC PATCH CABLE, DUPLEX
-  FIBER OPTIC TRANSCEIVER – SINGLE MODE
-  BLUETOOTH DETECTOR
-  TRAFFIC SIGNAL CONTROLLER
-  CCTV CAMERA, PAN-TILT-ZOOM
-  POWER OVER ETHERNET INJECTOR
-  UNINTERRUPTIBLE POWER SUPPLY

#### NOTES:

- DISTRIBUTION CABLE-FIBER (DCF) TUBES CONTAINING UNUSED FIBER STRANDS SHALL REMAIN UNCUT UNLESS OTHERWISE DIRECTED BY THE ENGINEER.
- TRUNK CABLE-FIBER (TCF) SHALL HAVE SLACK STORED WITHIN THE SPLICE COMMUNICATIONS VAULT AND SHALL PASS THROUGH UNCUT.
- UNSPLICED FIBER STRANDS SHALL BE COILED WITHIN SPLICE TRAY.
- FIBER-OPTIC CABLE DEPICTED IS GUIDANCE ONLY. ACTUAL FIBER-OPTIC CABLE FROM DMS CONTROLLER TO DMS DISPLAY SHALL BE IN ACCORDANCE WITH THE DMS MANUFACTURER'S REQUIREMENTS.
- REFER TO TRAFFIC SIGNAL PLANS AND INTERCONNECT SHEETS FOR ADDITIONAL INFORMATION.

ITS-37



DESIGNED - YJ  
DRAWN - MT  
CHECKED - RCB/KA  
DATE - 11-22-2024

REVISED -  
REVISED -  
REVISED -  
REVISED -

STATE OF ILLINOIS  
DEPARTMENT OF TRANSPORTATION


TRAFFIC SIGNAL FIBER SPLICING DIAGRAM (2 OF 2)  
CERMAK RD / 22ND ST. AND I-294 WEST RAMP

N.T.S. SHEET OF SHEETS STA. TO STA.

| F.A.P. RTE.        | SECTION             | COUNTY           | TOTAL SHEETS | SHEET NO. |
|--------------------|---------------------|------------------|--------------|-----------|
| 365                | 20-265-SUR, SW & TS | DUPAGE/COOK      | 492          | 376       |
| CONTRACT NO. 62N39 |                     |                  |              |           |
| ILLINOIS           |                     | FED. AID PROJECT |              |           |





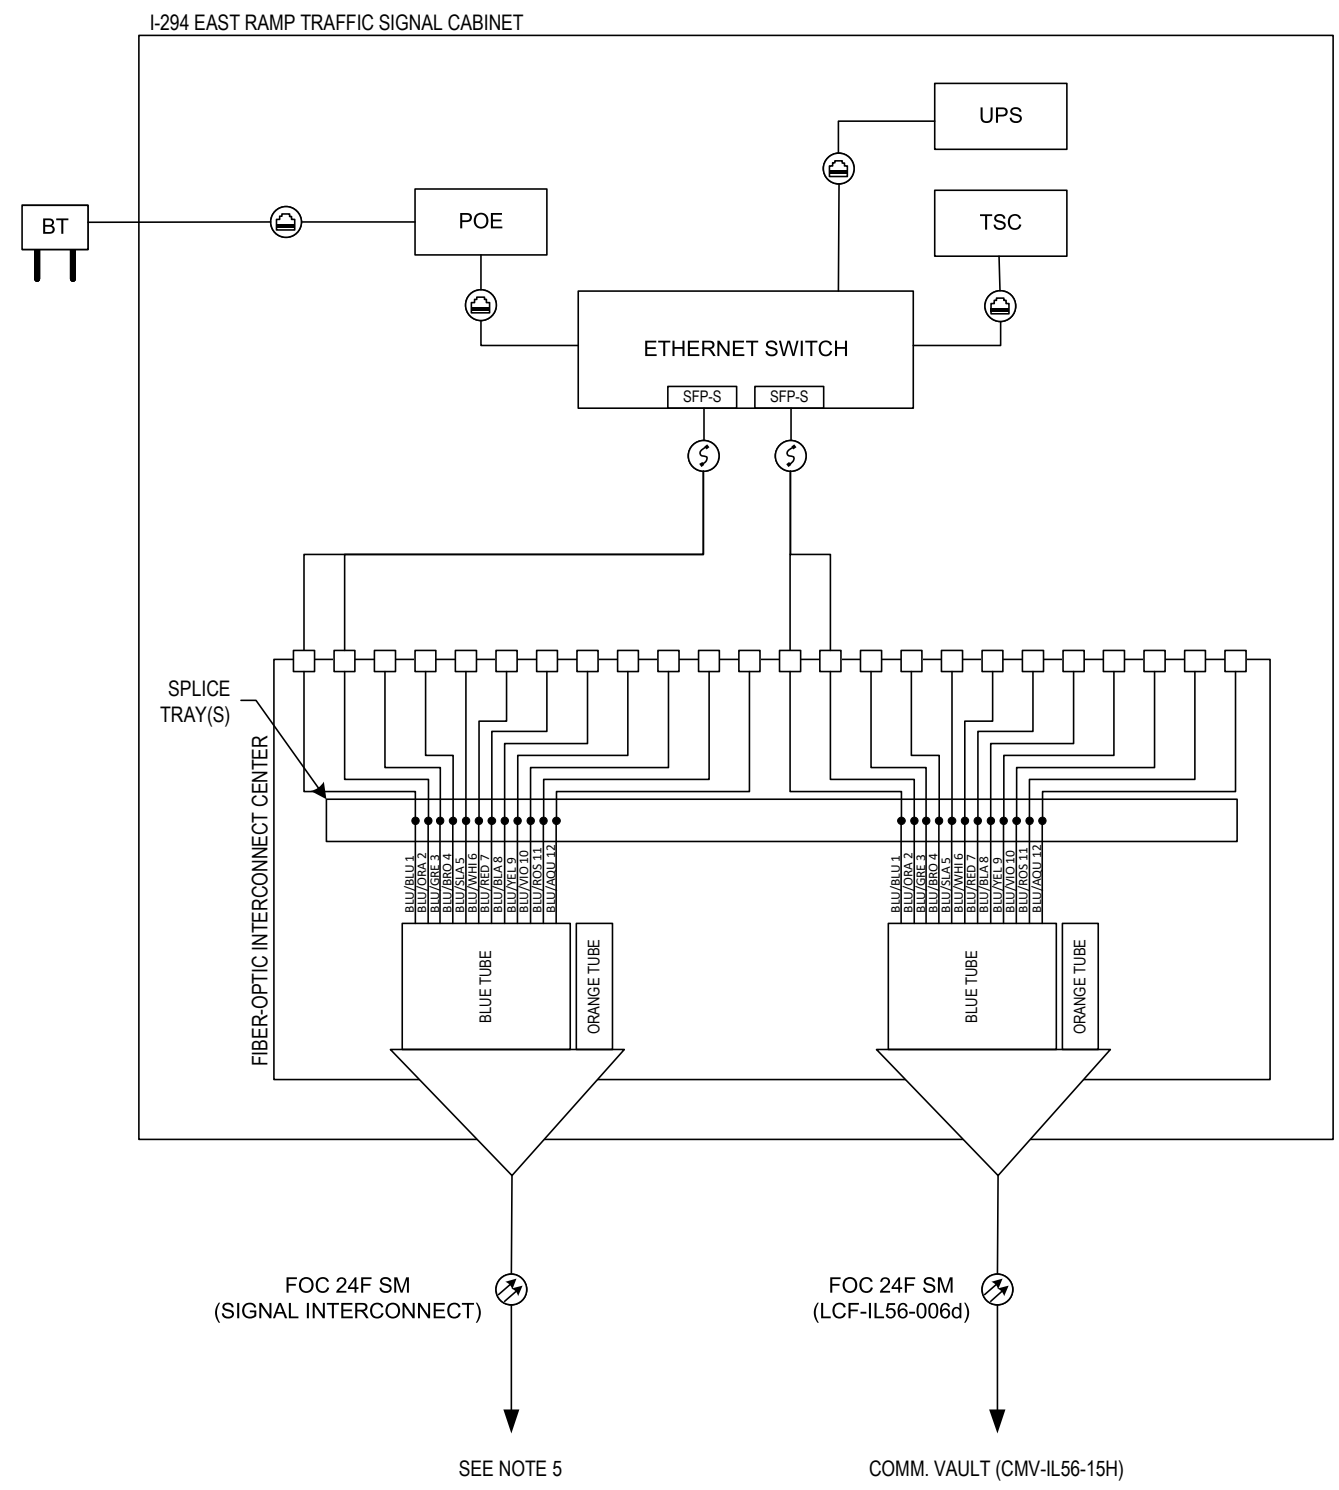

**LEGEND**


**PROPOSED**

- FIBER OPTIC CABLE (FOC)
- FIBER-OPTIC FUSION SPLICE
- FIBER PATCH PANEL PORT
- CAT 6 CABLE
- FIBER OPTIC PATCH CABLE, DUPLEX
- FIBER OPTIC TRANSCEIVER – SINGLE MODE
- BLUETOOTH DETECTOR
- TRAFFIC SIGNAL CONTROLLER
- CCTV CAMERA, PAN-TILT-ZOOM
- POWER OVER ETHERNET INJECTOR
- UNINTERRUPTIBLE POWER SUPPLY

- NOTES:**
- DISTRIBUTION CABLE-FIBER (DCF) TUBES CONTAINING UNUSED FIBER STRANDS SHALL REMAIN UNCUT UNLESS OTHERWISE DIRECTED BY THE ENGINEER.
  - TRUNK CABLE-FIBER (TCF) TUBES CONTAINING UNUSED FIBER STRANDS SHALL REMAIN UNCUT UNLESS OTHERWISE DIRECTED BY THE ENGINEER.
  - UNSPLICED FIBER STRANDS SHALL BE COILED WITHIN SPLICE TRAY.
  - FIBER-OPTIC CABLE DEPICTED IS GUIDANCE ONLY. ACTUAL FIBER-OPTIC CABLE FROM DMS CONTROLLER TO DMS DISPLAY SHALL BE IN ACCORDANCE WITH THE DMS MANUFACTURER'S REQUIREMENTS.
  - REFER TO TRAFFIC SIGNAL PLANS AND INTERCONNECT SHEETS FOR ADDITIONAL INFORMATION.





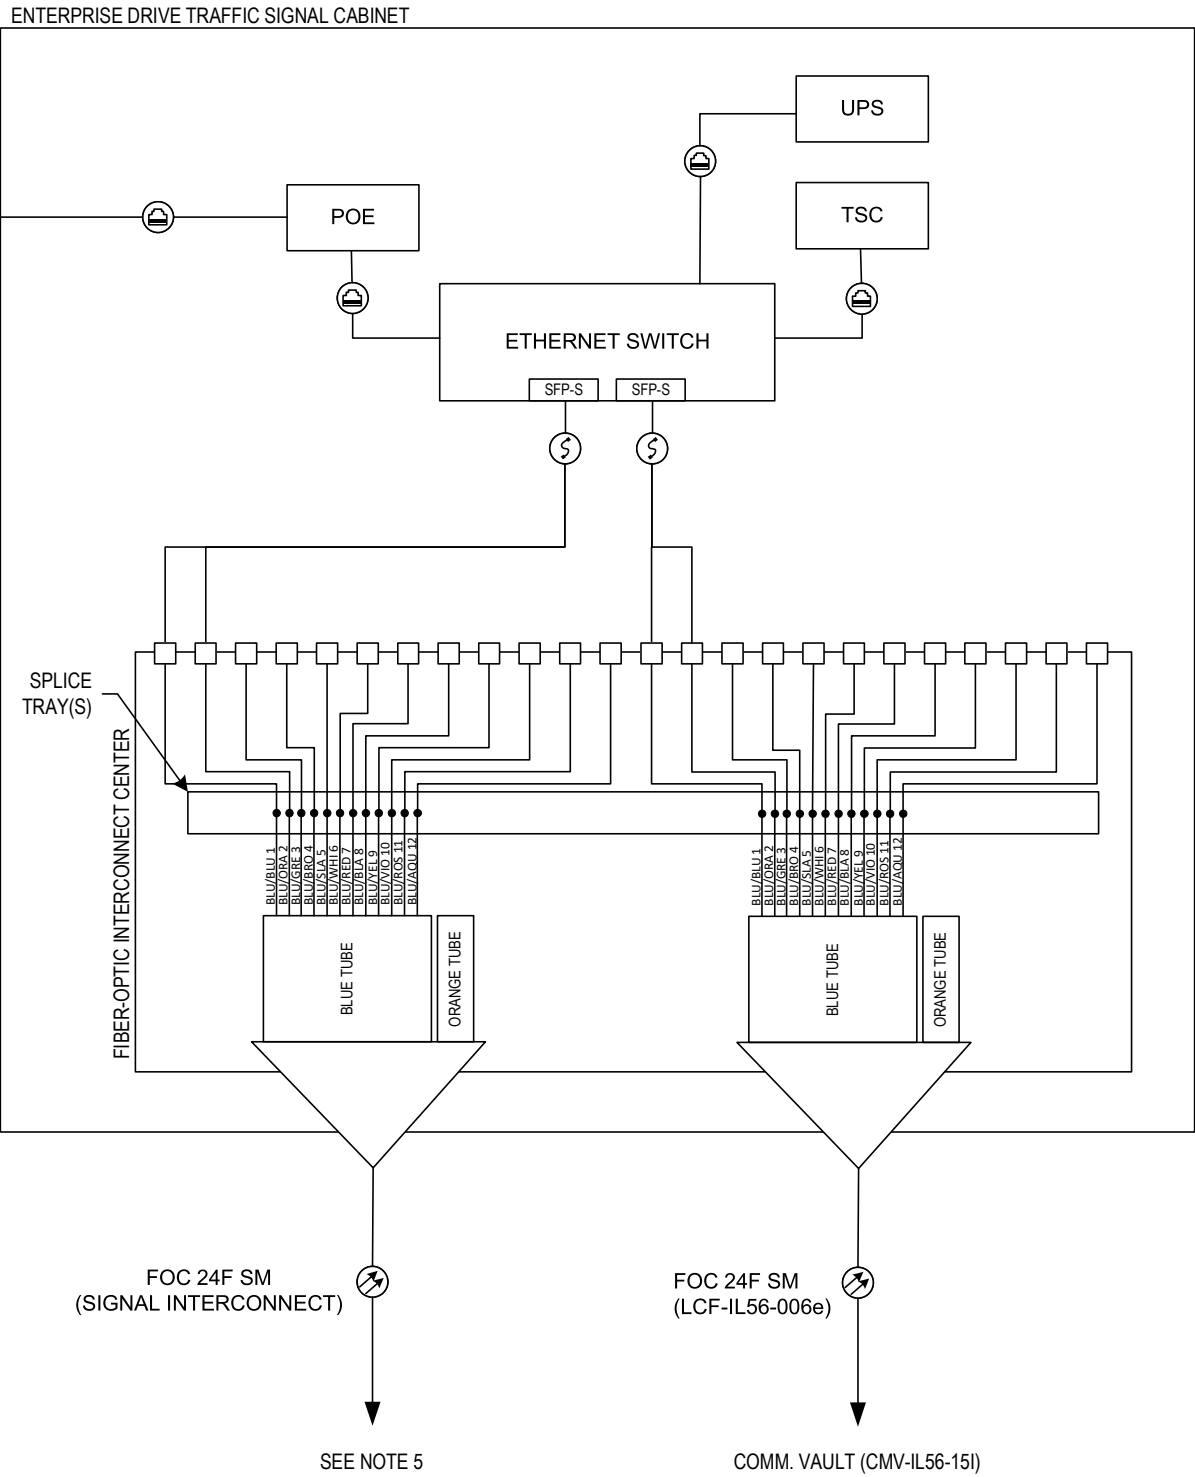

**LEGEND**


**PROPOSED**

- FIBER OPTIC CABLE (FOC)
- FIBER-OPTIC FUSION SPLICE
- FIBER PATCH PANEL PORT
- CAT 6 CABLE
- FIBER OPTIC PATCH CABLE, DUPLEX
- FIBER OPTIC TRANSCEIVER – SINGLE MODE
- BLUETOOTH DETECTOR
- TRAFFIC SIGNAL CONTROLLER
- CCTV CAMERA, PAN-TILT-ZOOM
- POWER OVER ETHERNET INJECTOR
- UNINTERRUPTIBLE POWER SUPPLY

- NOTES:**
- DISTRIBUTION CABLE-FIBER (DCF) TUBES CONTAINING UNUSED FIBER STRANDS SHALL REMAIN UNCUT UNLESS OTHERWISE DIRECTED BY THE ENGINEER.
  - TRUNK CABLE-FIBER (TCF) SHALL HAVE SLACK STORED WITHIN THE SPLICE COMMUNICATIONS VAULT AND SHALL PASS THROUGH UNCUT.
  - UNSPLICED FIBER STRANDS SHALL BE COILED WITHIN SPLICE TRAY.
  - FIBER-OPTIC CABLE DEPICTED IS GUIDANCE ONLY. ACTUAL FIBER-OPTIC CABLE FROM DMS CONTROLLER TO DMS DISPLAY SHALL BE IN ACCORDANCE WITH THE DMS MANUFACTURER'S REQUIREMENTS.
  - REFER TO TRAFFIC SIGNAL PLANS AND INTERCONNECT SHEETS FOR ADDITIONAL INFORMATION.

ITS-41



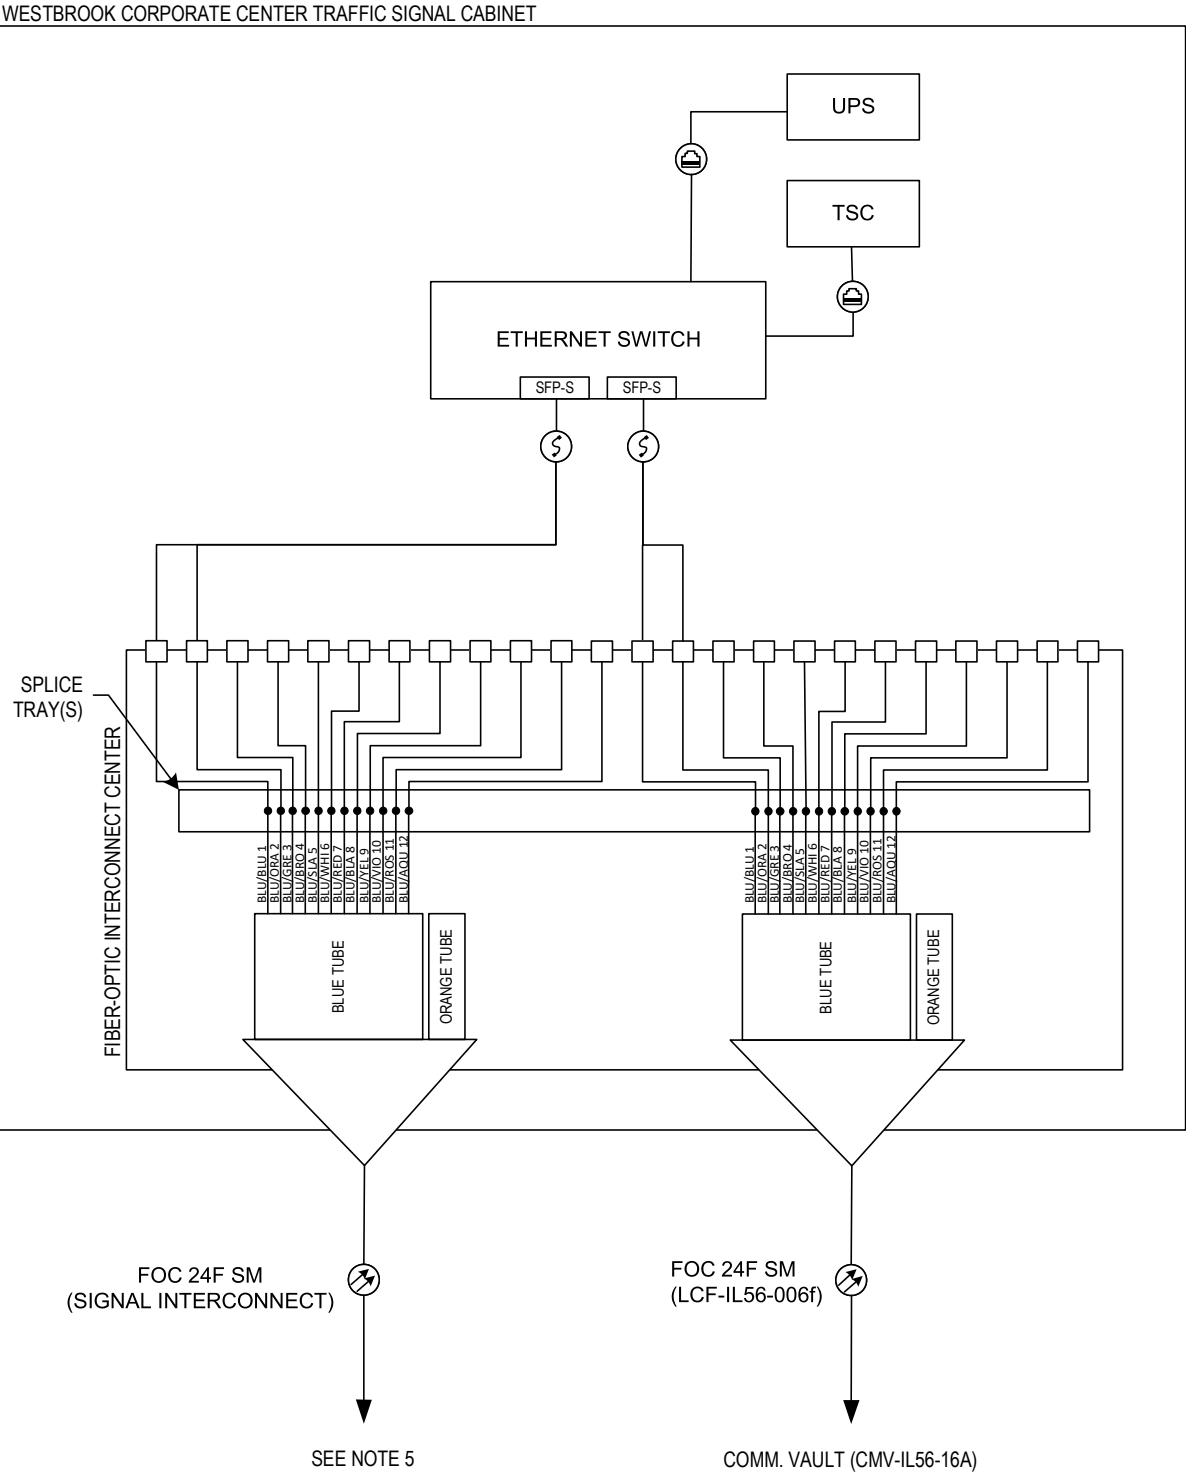


**LEGEND**

**PROPOSED**

- FIBER OPTIC CABLE (FOC)
- FIBER-OPTIC FUSION SPLICE
- FIBER PATCH PANEL PORT
- CAT 6 CABLE
- FIBER OPTIC PATCH CABLE, DUPLEX
- FIBER OPTIC TRANSCEIVER – SINGLE MODE
- BLUETOOTH DETECTOR
- TRAFFIC SIGNAL CONTROLLER
- CCTV CAMERA, PAN-TILT-ZOOM
- POWER OVER ETHERNET INJECTOR
- UNINTERRUPTIBLE POWER SUPPLY

- NOTES:**
- DISTRIBUTION CABLE-FIBER (DCF) TUBES CONTAINING UNUSED FIBER STRANDS SHALL REMAIN UNCUT UNLESS OTHERWISE DIRECTED BY THE ENGINEER.
  - TRUNK CABLE-FIBER (TCF) SHALL HAVE SLACK STORED WITHIN THE SPLICE COMMUNICATIONS VAULT AND SHALL PASS THROUGH UNCUT.
  - UNSPLICED FIBER STRANDS SHALL BE COILED WITHIN SPLICE TRAY.
  - FIBER-OPTIC CABLE DEPICTED IS GUIDANCE ONLY. ACTUAL FIBER-OPTIC CABLE FROM DMS CONTROLLER TO DMS DISPLAY SHALL BE IN ACCORDANCE WITH THE DMS MANUFACTURER'S REQUIREMENTS.
  - REFER TO TRAFFIC SIGNAL PLANS AND INTERCONNECT SHEETS FOR ADDITIONAL INFORMATION.

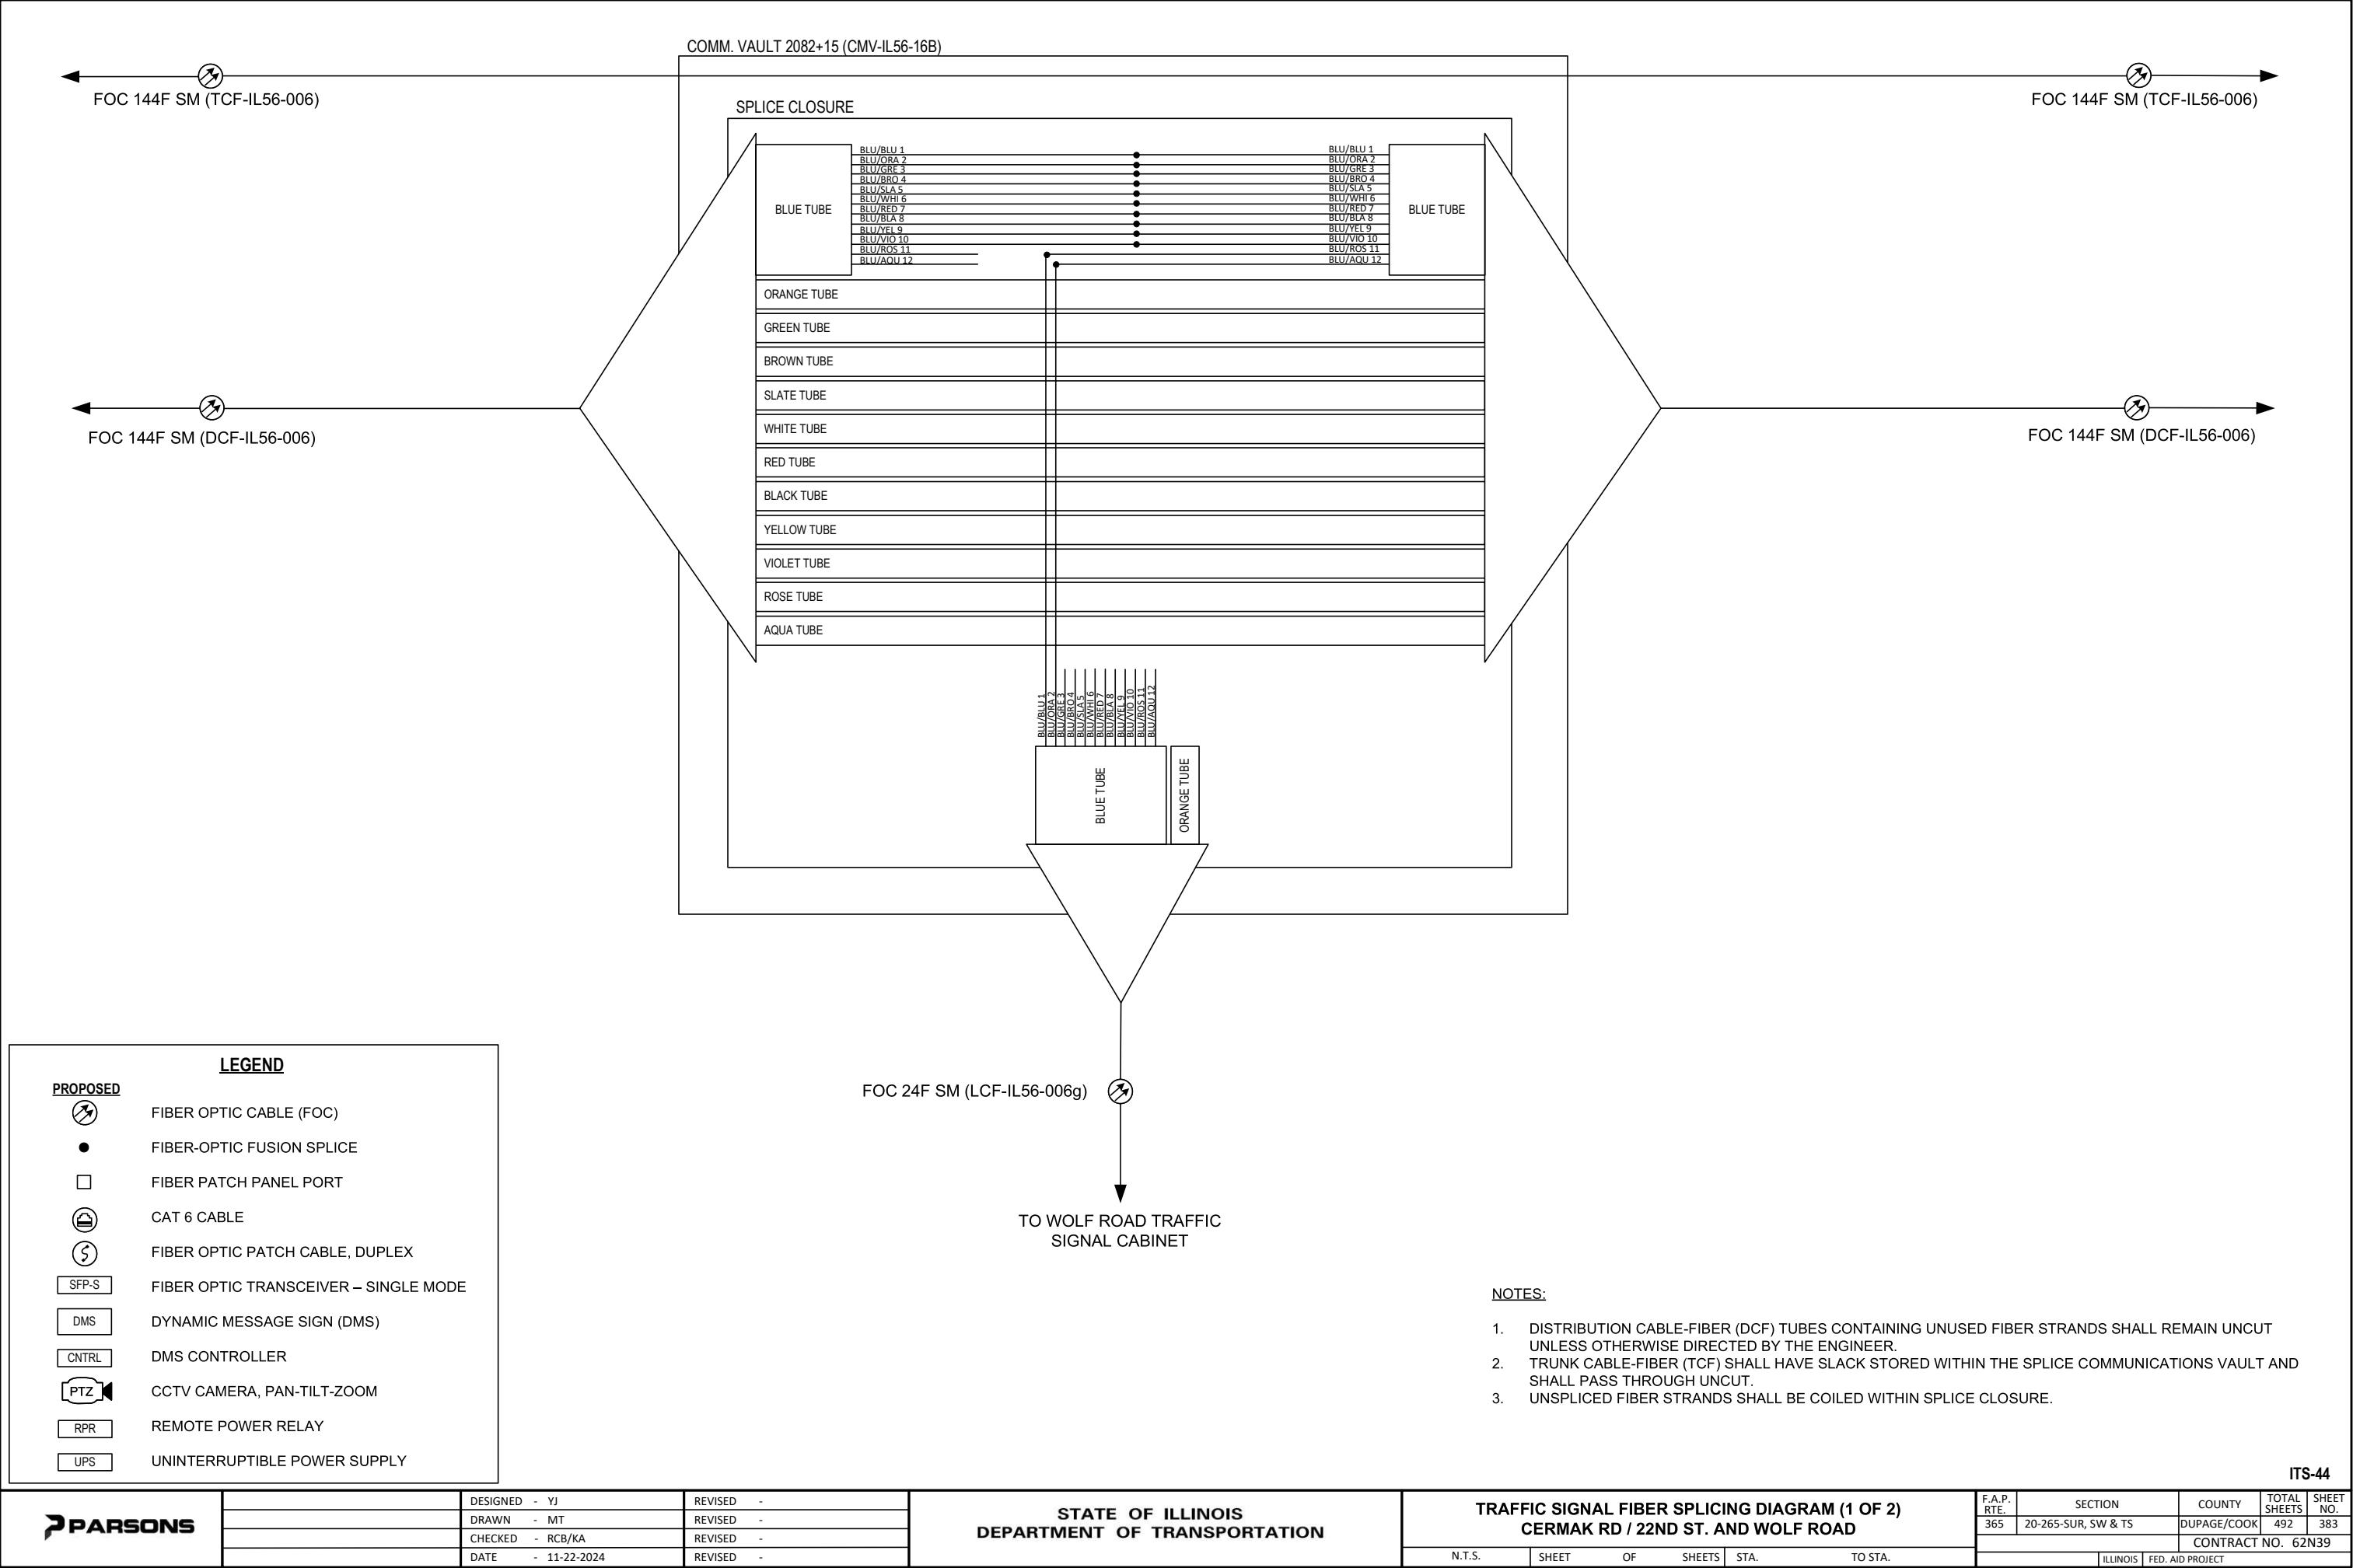

UPS

UNINTERRUPTIBLE POWER SUPPLY

NOTES:

1. DISTRIBUTION CABLE-FIBER (DCF) TUBES CONTAINING UNUSED FIBER STRANDS SHALL REMAIN UNCUT UNLESS OTHERWISE DIRECTED BY THE ENGINEER.

2. TRUNK CABLE-FIBER (TCF) SHALL HAVE SLACK STORED WITHIN THE SPLICE COMMUNICATIONS VAULT AND SHALL PASS THROUGH UNCUT.

3. UNSPLICED FIBER STRANDS SHALL BE COILED WITHIN SPLICE CLOSURE.

PARSONS

DESIGNED - YJ

DRAWN - MT

CHECKED - RCB/KA

DATE - 11-22-2024

REVISED -

REVISED -

REVISED -

REVISED -

STATE OF ILLINOIS

DEPARTMENT OF TRANSPORTATION

TRAFFIC SIGNAL FIBER SPLICING DIAGRAM (1 OF 2)

CERMAK RD / 22ND ST. AND WOLF ROAD

N.T.S.

SHEET

OF

SHEETS

STA.

TO STA.

F.A.P. RTE.

365

SECTION

20-265-SUR, SW & TS

COUNTY

DUPAGE/COOK

TOTAL SHEETS

492

SHEET NO.

383


CONTRACT NO.

62N39

ILLINOIS

FED. AID PROJECT

ITS-44

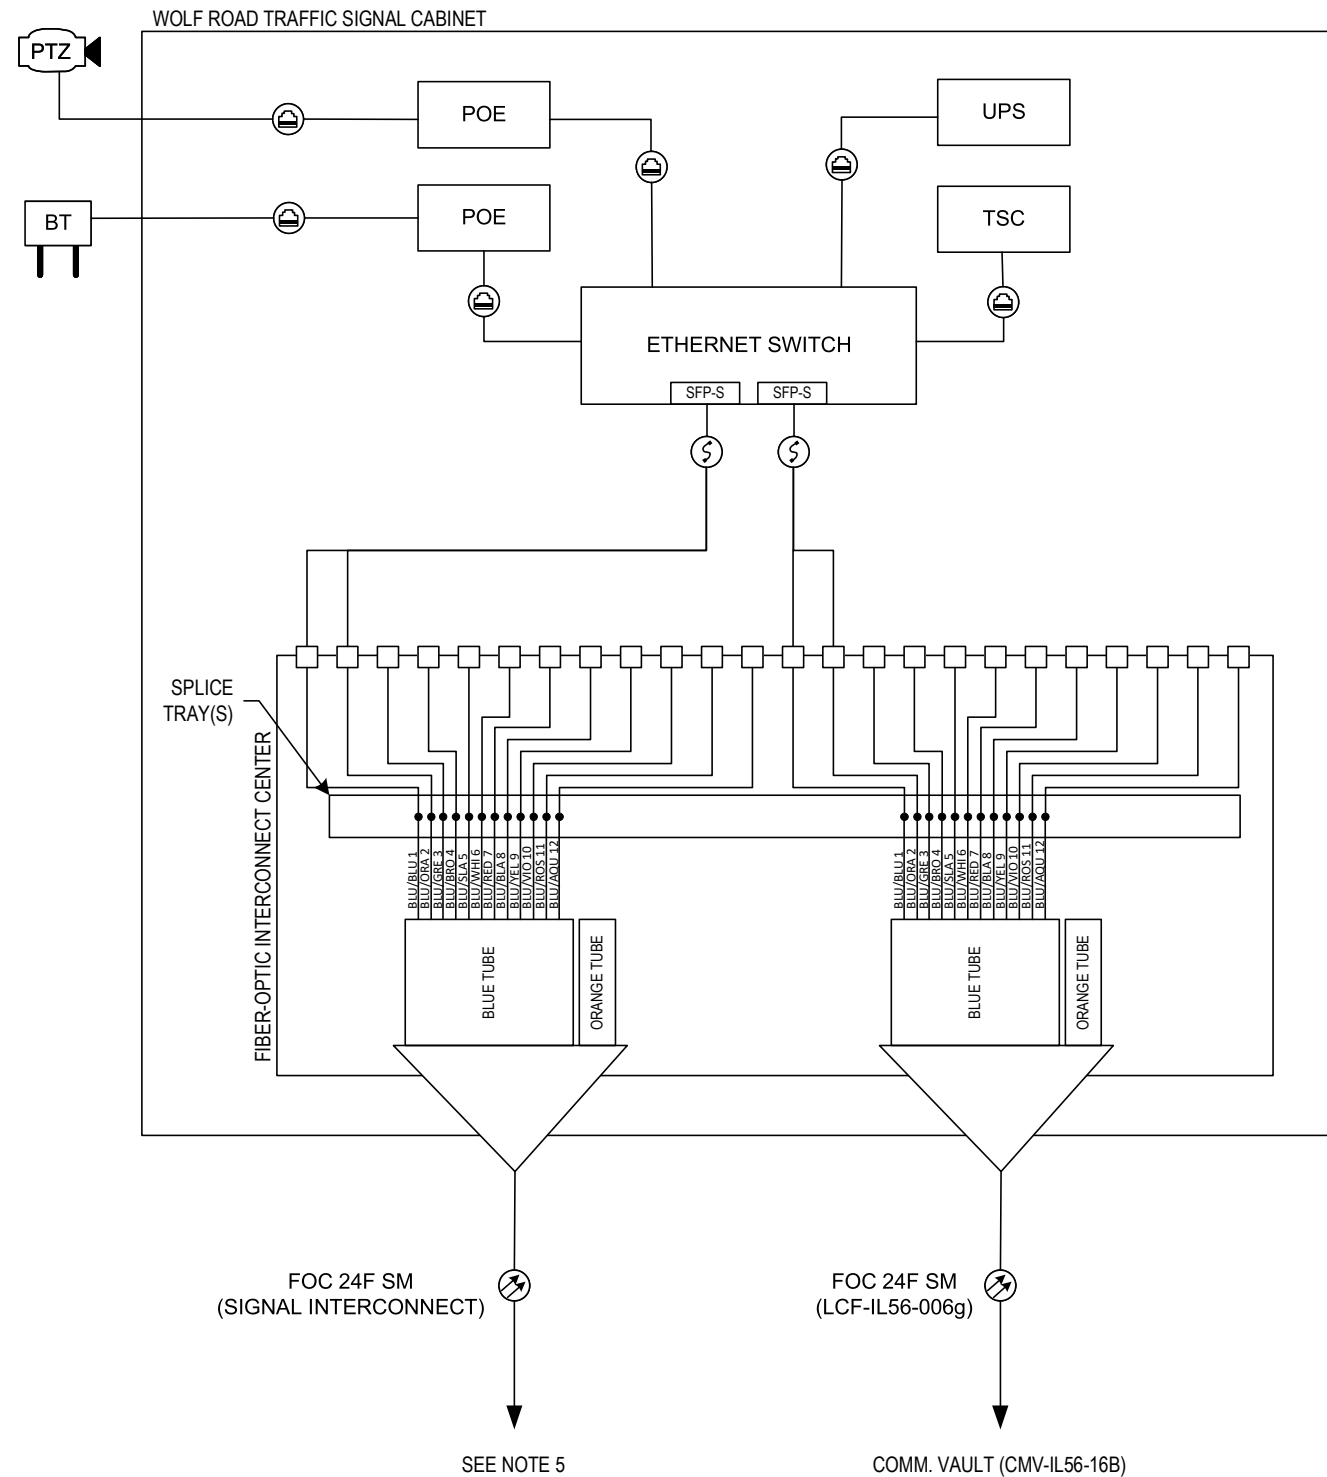

**LEGEND**

**PROPOSED**

- FIBER OPTIC CABLE (FOC)
- FIBER-OPTIC FUSION SPLICE
- FIBER PATCH PANEL PORT
- CAT 6 CABLE
- FIBER OPTIC PATCH CABLE, DUPLEX
- FIBER OPTIC TRANSCEIVER – SINGLE MODE
- BLUETOOTH DETECTOR
- TRAFFIC SIGNAL CONTROLLER
- CCTV CAMERA, PAN-TILT-ZOOM
- POWER OVER ETHERNET INJECTOR
- UNINTERRUPTIBLE POWER SUPPLY

**NOTES:**

- DISTRIBUTION CABLE-FIBER (DCF) TUBES CONTAINING UNUSED FIBER STRANDS SHALL REMAIN UNCUT UNLESS OTHERWISE DIRECTED BY THE ENGINEER.
- TRUNK CABLE-FIBER (TCF) SHALL HAVE SLACK STORED WITHIN THE SPLICE COMMUNICATIONS VAULT AND SHALL PASS THROUGH UNCUT.
- UNSPLICED FIBER STRANDS SHALL BE COILED WITHIN SPLICE TRAY.
- FIBER-OPTIC CABLE DEPICTED IS GUIDANCE ONLY. ACTUAL FIBER-OPTIC CABLE FROM DMS CONTROLLER TO DMS DISPLAY SHALL BE IN ACCORDANCE WITH THE DMS MANUFACTURER'S REQUIREMENTS.
- REFER TO TRAFFIC SIGNAL PLANS AND INTERCONNECT SHEETS FOR ADDITIONAL INFORMATION.

ITS-45



DESIGNED - YJ  
DRAWN - MT  
CHECKED - RCB/KA  
DATE - 11-22-2024


REVISED -  
REVISED -  
REVISED -  
REVISED -

STATE OF ILLINOIS  
DEPARTMENT OF TRANSPORTATION

TRAFFIC SIGNAL FIBER SPLICING DIAGRAM (2 OF 2)  
CERMAK RD / 22ND ST. AND WOLF ROAD



N.T.S. SHEET OF SHEETS STA. TO STA.

| F.A.P. RTE.               | SECTION             | COUNTY      | TOTAL SHEETS | SHEET NO. |
|---------------------------|---------------------|-------------|--------------|-----------|
| 365                       | 20-265-SUR, SW & TS | DUPAGE/COOK | 492          | 384       |
| CONTRACT NO. 62N39        |                     |             |              |           |
| ILLINOIS FED. AID PROJECT |                     |             |              |           |

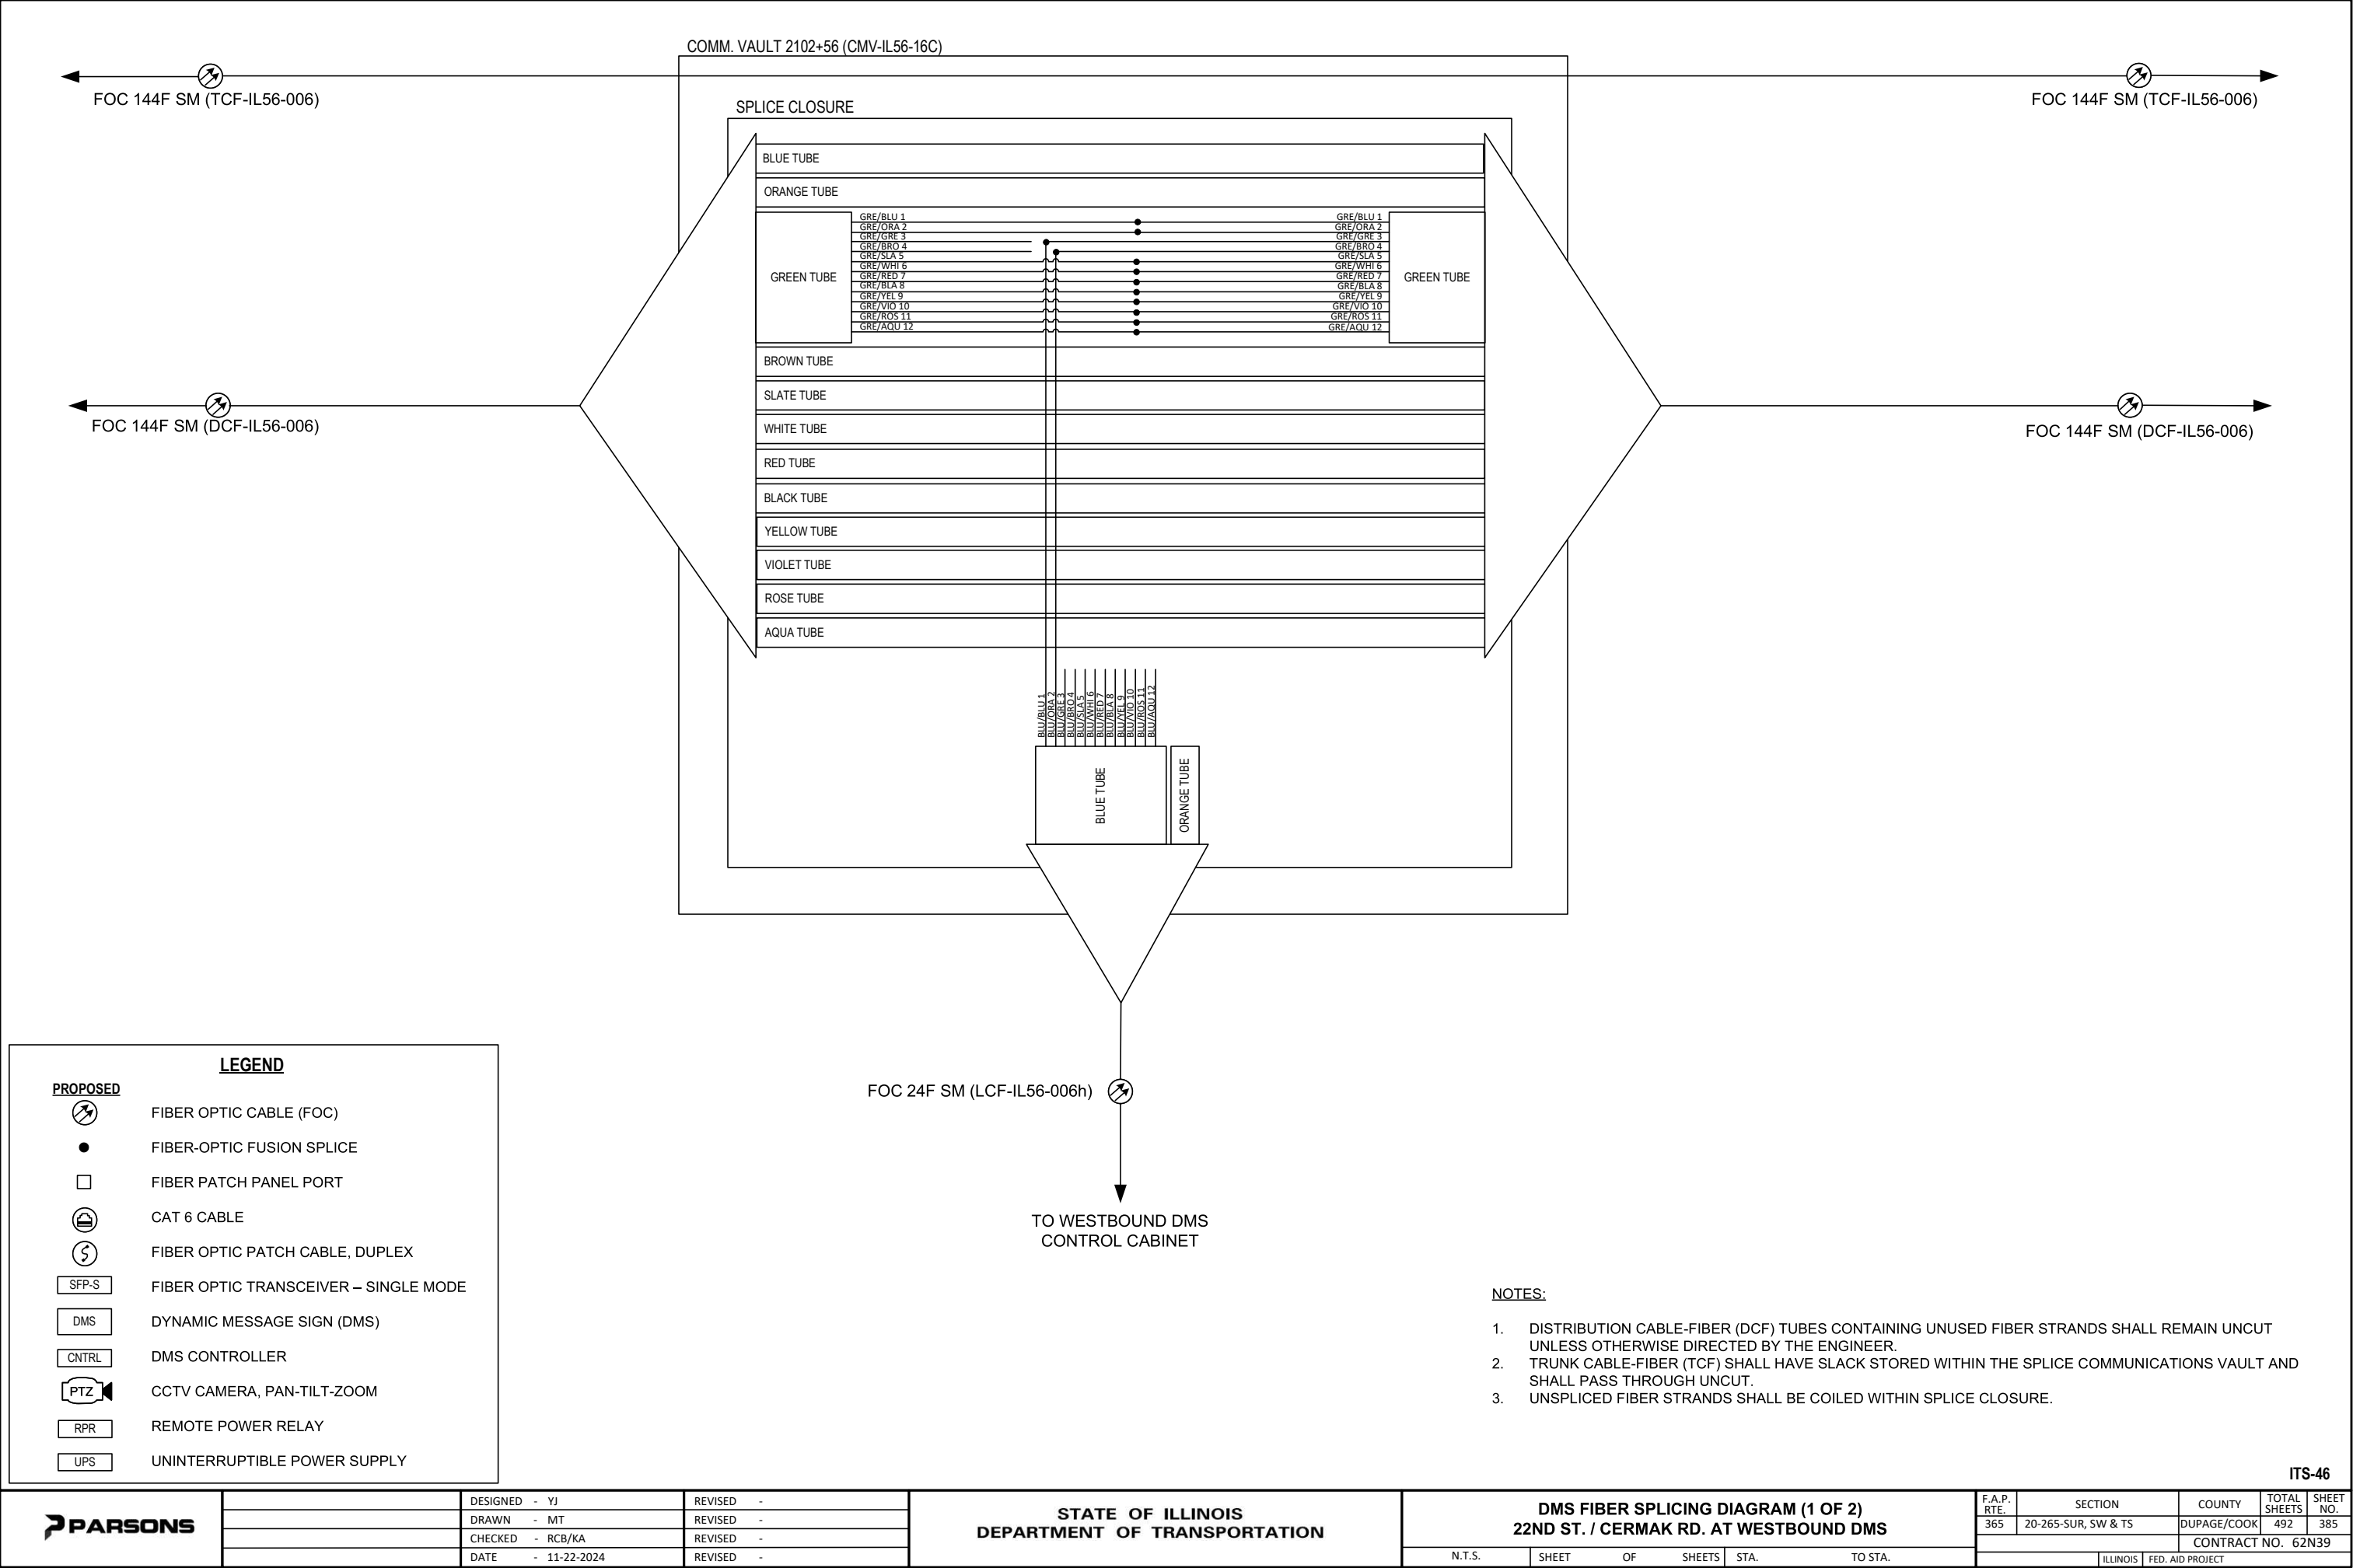



DMS CONTROL CABINET (WB DMS)

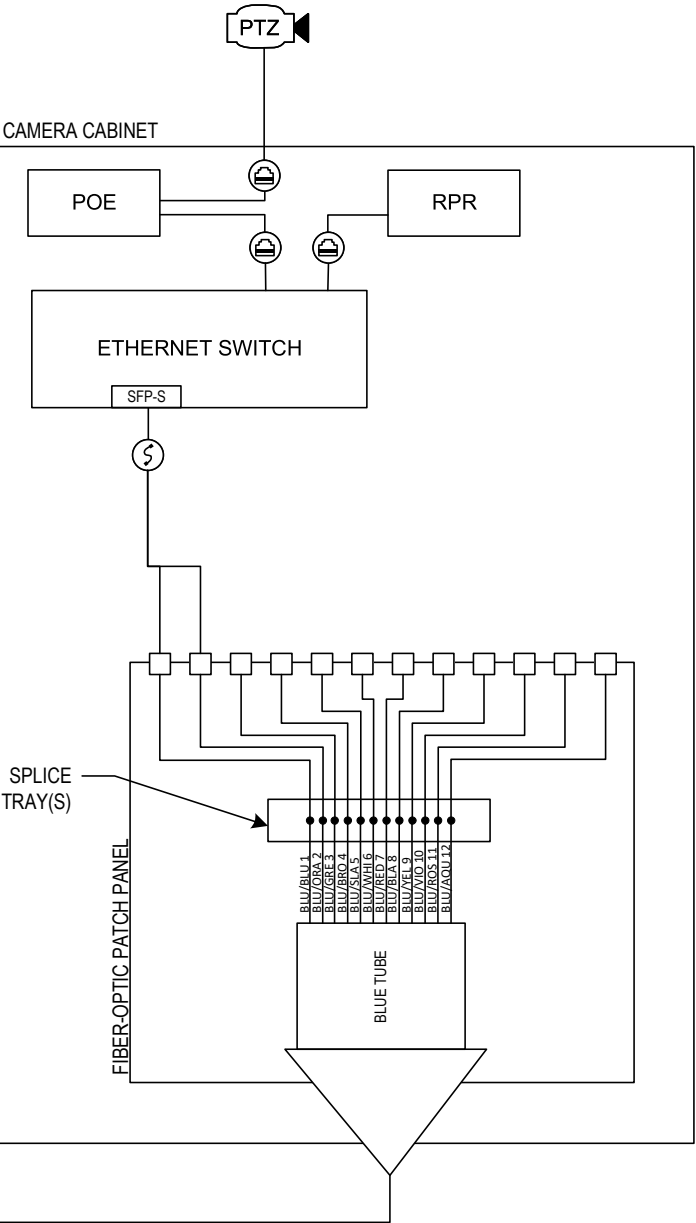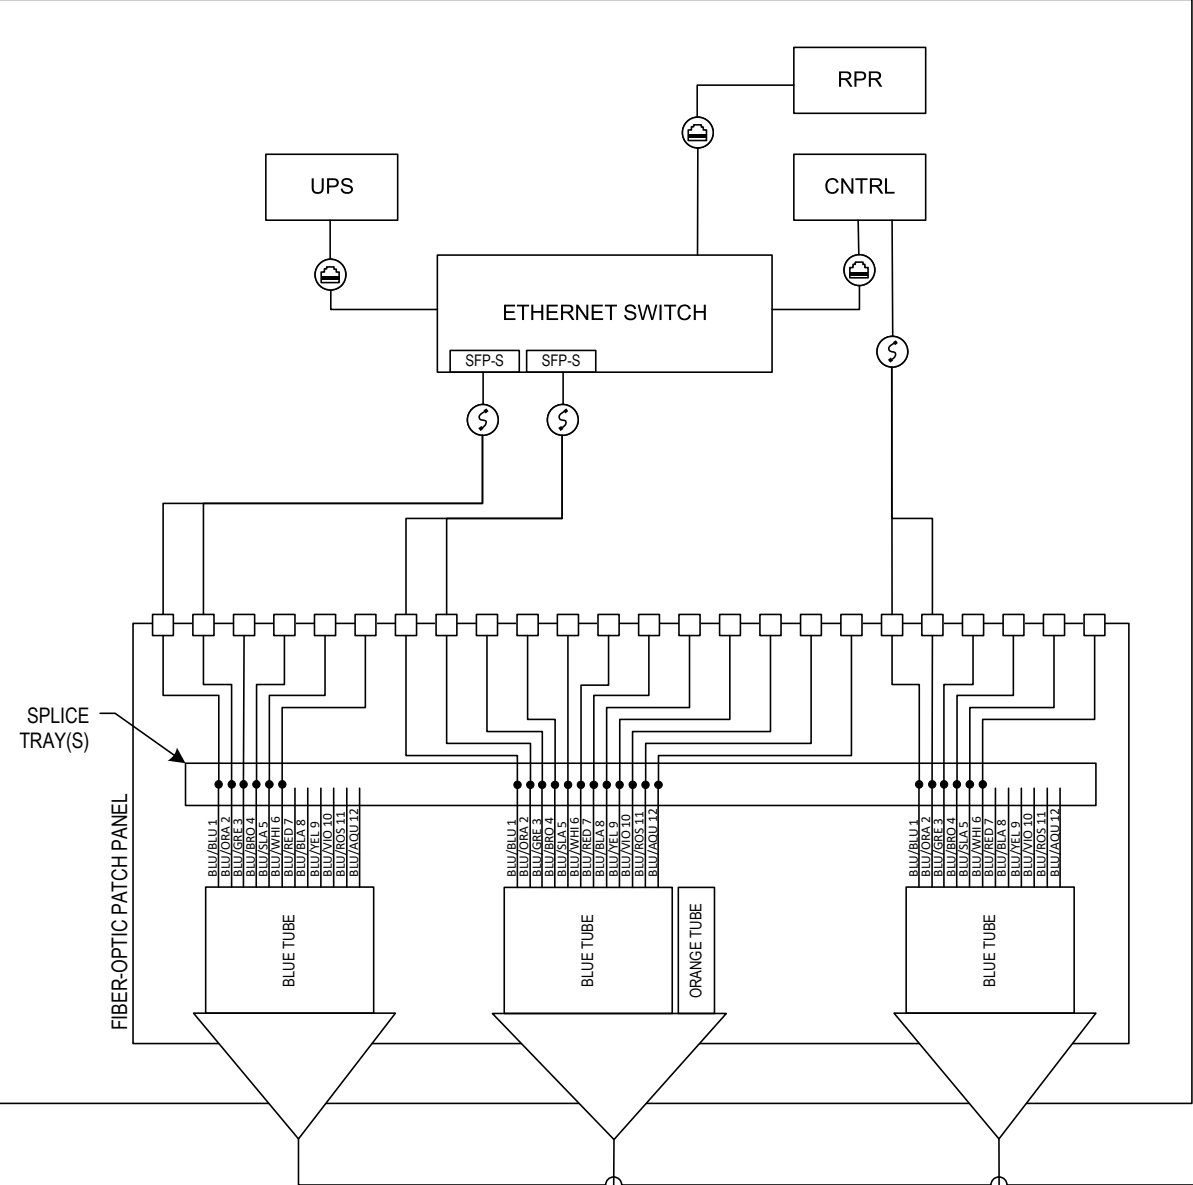

LEGEND

PROPOSED



FIBER OPTIC CABLE (FOC)



FIBER-OPTIC FUSION SPLICE



FIBER PATCH PANEL PORT



CAT 6 CABLE



FIBER OPTIC PATCH CABLE, DUPLEX



FIBER OPTIC TRANSCEIVER – SINGLE MODE



DYNAMIC MESSAGE SIGN (DMS)



DMS CONTROLLER



CCTV CAMERA, PAN-TILT-ZOOM



REMOTE POWER RELAY



UNINTERRUPTIBLE POWER SUPPLY

FOC 12F SM

FOC 24F SM  
(LCF-IL56-006h)

FOC PER DMS MANUFACTURER  
(SEE NOTE 4)

COMM. VAULT 2102+56  
(CMV-IL56-16C)

TO DMS DISPLAY

NOTES:

- DISTRIBUTION CABLE-FIBER (DCF) TUBES CONTAINING UNUSED FIBER STRANDS SHALL REMAIN UNCUT UNLESS OTHERWISE DIRECTED BY THE ENGINEER.
- TRUNK CABLE-FIBER (TCF) SHALL HAVE SLACK STORED WITHIN THE SPLICE COMMUNICATIONS VAULT AND SHALL PASS THROUGH UNCUT.
- UNSPLICED FIBER STRANDS SHALL BE COILED WITHIN SPLICE TRAY.
- FIBER-OPTIC CABLE DEPICTED IS GUIDANCE ONLY. ACTUAL FIBER-OPTIC CABLE FROM DMS CONTROLLER TO DMS DISPLAY SHALL BE IN ACCORDANCE WITH THE DMS MANUFACTURER'S REQUIREMENTS.

ITS-47

PARSONS

DESIGNED - YJ  
DRAWN - MT  
CHECKED - RCB/KA  
DATE - 11-22-2024

REVISED -  
REVISED -  
REVISED -  
REVISED -

STATE OF ILLINOIS  
DEPARTMENT OF TRANSPORTATION


DMS FIBER SPLICING DIAGRAM (2 OF 2)  
22ND ST. / CERMAK RD. AT WESTBOUND DMS

N.T.S. SHEET OF SHEETS STA. TO STA.

| F.A.P. RTE.        | SECTION             | COUNTY           | TOTAL SHEETS | SHEET NO. |
|--------------------|---------------------|------------------|--------------|-----------|
| 365                | 20-265-SUR, SW & TS | DUPAGE/COOK      | 492          | 386       |
| CONTRACT NO. 62N39 |                     |                  |              |           |
| ILLINOIS           |                     | FED. AID PROJECT |              |           |





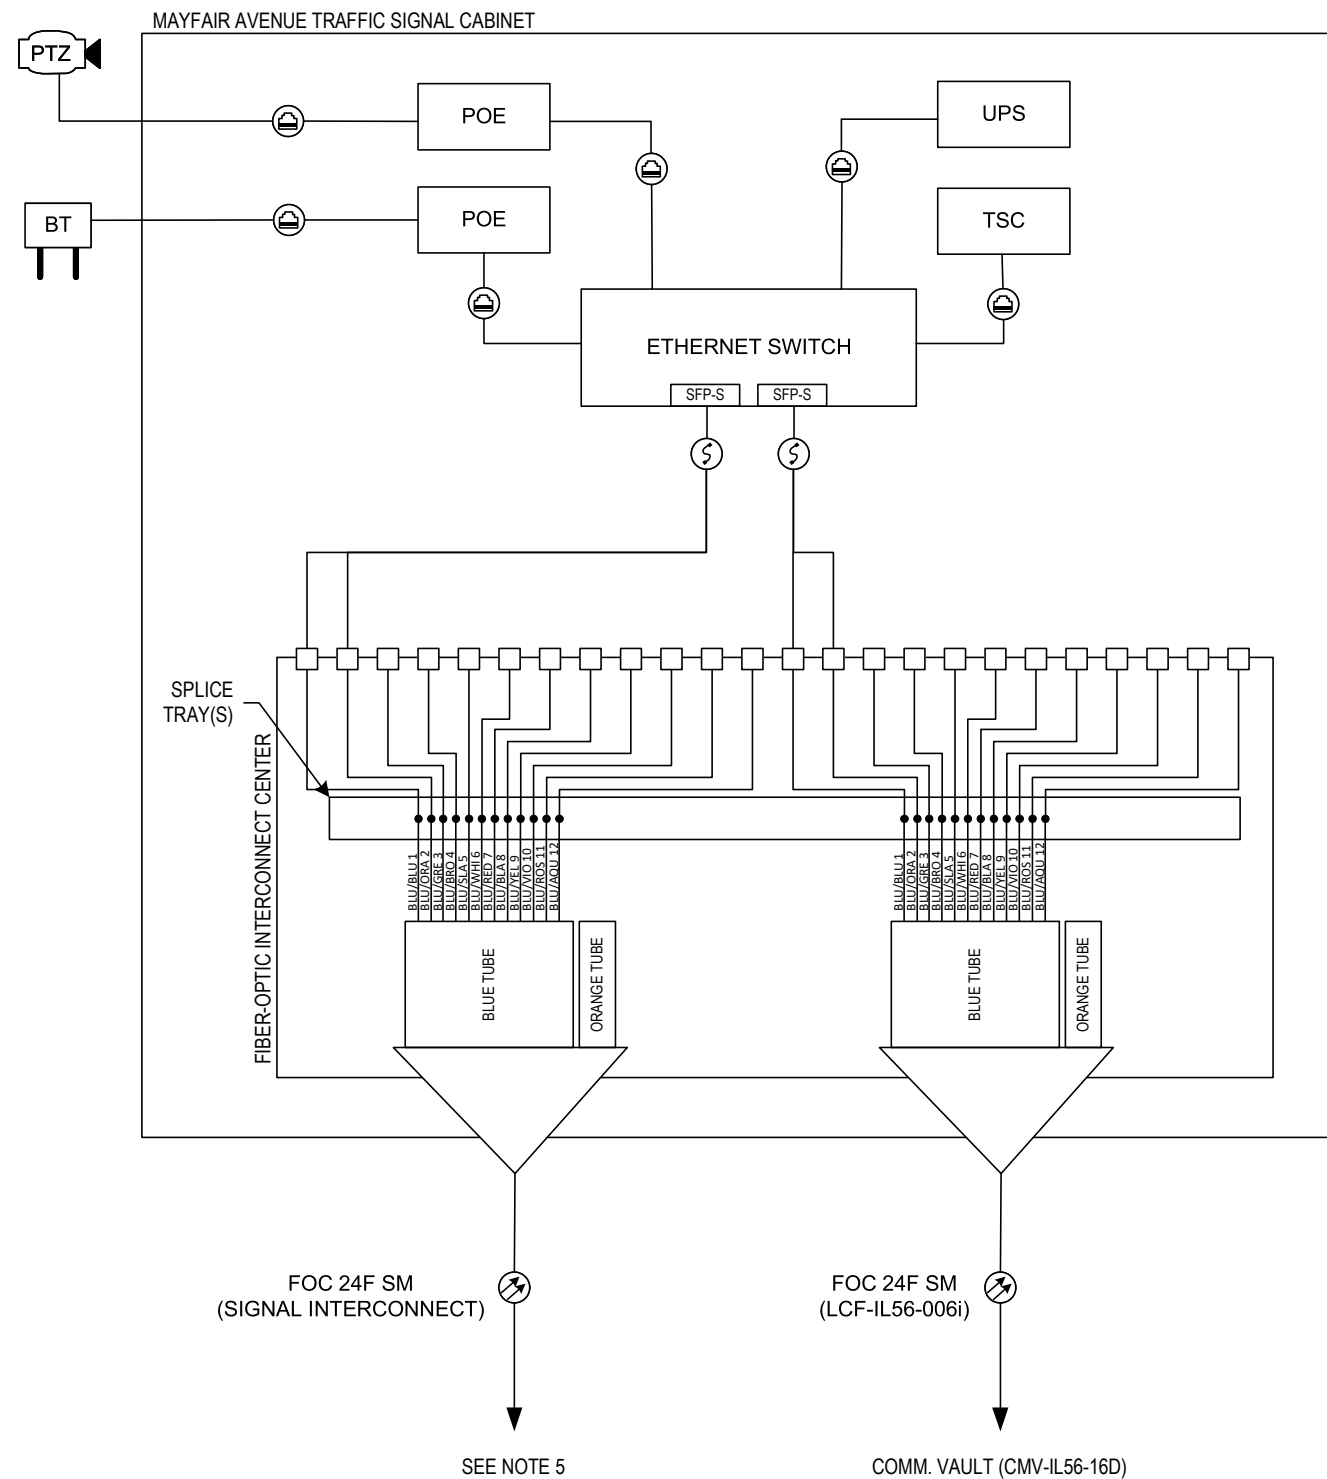

**LEGEND**

**PROPOSED**

- FIBER OPTIC CABLE (FOC)
- FIBER-OPTIC FUSION SPLICE
- FIBER PATCH PANEL PORT
- CAT 6 CABLE
- FIBER OPTIC PATCH CABLE, DUPLEX
- FIBER OPTIC TRANSCEIVER – SINGLE MODE
- BLUETOOTH DETECTOR
- TRAFFIC SIGNAL CONTROLLER
- CCTV CAMERA, PAN-TILT-ZOOM
- POWER OVER ETHERNET INJECTOR
- UNINTERRUPTIBLE POWER SUPPLY

**NOTES:**

- DISTRIBUTION CABLE-FIBER (DCF) TUBES CONTAINING UNUSED FIBER STRANDS SHALL REMAIN UNCUT UNLESS OTHERWISE DIRECTED BY THE ENGINEER.
- TRUNK CABLE-FIBER (TCF) SHALL HAVE SLACK STORED WITHIN THE SPLICE COMMUNICATIONS VAULT AND SHALL PASS THROUGH UNCUT.
- UNSPLICED FIBER STRANDS SHALL BE COILED WITHIN SPLICE TRAY.
- FIBER-OPTIC CABLE DEPICTED IS GUIDANCE ONLY. ACTUAL FIBER-OPTIC CABLE FROM DMS CONTROLLER TO DMS DISPLAY SHALL BE IN ACCORDANCE WITH THE DMS MANUFACTURER'S REQUIREMENTS.
- REFER TO TRAFFIC SIGNAL PLANS AND INTERCONNECT SHEETS FOR ADDITIONAL INFORMATION.

ITS-49



DESIGNED - YJ  
DRAWN - MT  
CHECKED - RCB/KA  
DATE - 11-22-2024

REVISED -  
REVISED -  
REVISED -  
REVISED -

STATE OF ILLINOIS  
DEPARTMENT OF TRANSPORTATION

TRAFFIC SIGNAL FIBER SPLICING DIAGRAM (2 OF 2)  
CERMAK RD / 22ND ST. AND MAYFAIR AVENUE

N.T.S. SHEET OF SHEETS STA. TO STA.

| F.A.P. RTE.               | SECTION             | COUNTY      | TOTAL SHEETS | SHEET NO. |
|---------------------------|---------------------|-------------|--------------|-----------|
| 365                       | 20-265-SUR, SW & TS | DUPAGE/COOK | 492          | 388       |
| CONTRACT NO. 62N39        |                     |             |              |           |
| ILLINOIS FED. AID PROJECT |                     |             |              |           |

SPLICE CLOSURE

FOC 144F SM (TCF-IL56-006)

FOC 144F SM (TCF-IL56-007)

FOC 144F SM (DCF-IL56-006)

FOC 144F SM (DCF-IL56-007)

LEGEND

PROPOSED



FIBER OPTIC CABLE (FOC)



FIBER-OPTIC FUSION SPLICE



FIBER PATCH PANEL PORT



CAT 6 CABLE



FIBER OPTIC PATCH CABLE, DUPLEX

SFP-S

FIBER OPTIC TRANSCEIVER – SINGLE MODE

DMS

DYNAMIC MESSAGE SIGN (DMS)

CNTRL

DMS CONTROLLER

PTZ


CCTV CAMERA, PAN-TILT-ZOOM

RPR

REMOTE POWER RELAY

UPS

UNINTERRUPTIBLE POWER SUPPLY

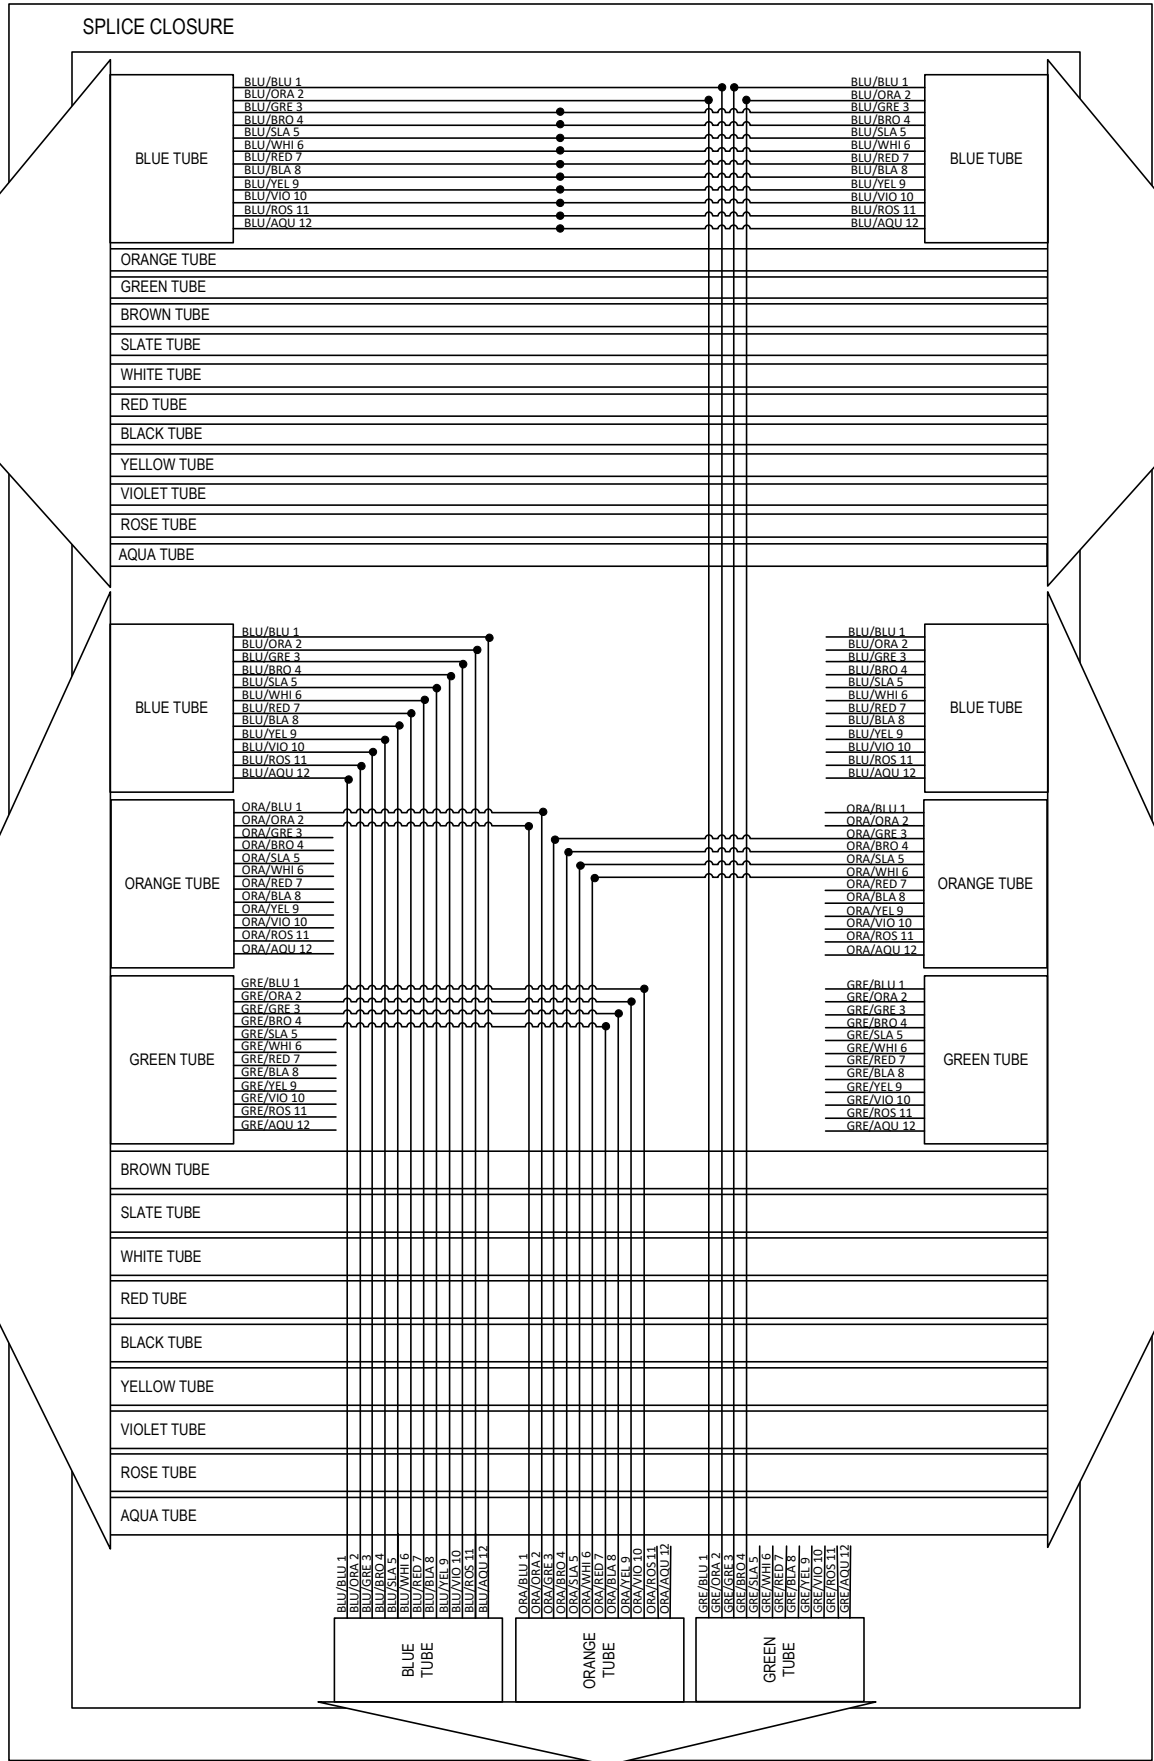

FOC 36F SM (LCF-IL56-007a)

NOTES:

- DISTRIBUTION CABLE-FIBER (DCF) TUBES CONTAINING UNUSED FIBER STRANDS SHALL REMAIN UNCUT UNLESS OTHERWISE DIRECTED BY THE ENGINEER.
- TRUNK CABLE-FIBER (TCF) TUBES CONTAINING UNUSED FIBER STRANDS SHALL REMAIN UNCUT UNLESS OTHERWISE DIRECTED BY THE ENGINEER.
- UNSPliced FIBER STRANDS SHALL BE COILED WITHIN SPLICE CLOSURE.

TO US 12-20-45 (LAGRANGE RD/MANNHEIM RD) TRAFFIC SIGNAL CABINET

ITS-50



DESIGNED - YJ  
DRAWN - MT  
CHECKED - RCB/KA  
DATE - 11-22-2024


REVISED -  
REVISED -  
REVISED -  
REVISED -

STATE OF ILLINOIS  
DEPARTMENT OF TRANSPORTATION

TRAFFIC SIGNAL FIBER SPLICING DIAGRAM (1 OF 2)  
CERMAK RD / 22ND ST. AND US 12-20-45 (LAGRANGE/MANNHEIM)

N.T.S. SHEET OF SHEETS STA. TO STA.

| F.A.P. RTE.               | SECTION             | COUNTY      | TOTAL SHEETS | SHEET NO. |
|---------------------------|---------------------|-------------|--------------|-----------|
| 365                       | 20-265-SUR, SW & TS | DUPAGE/COOK | 492          | 389       |
| CONTRACT NO. 62N39        |                     |             |              |           |
| ILLINOIS FED. AID PROJECT |                     |             |              |           |

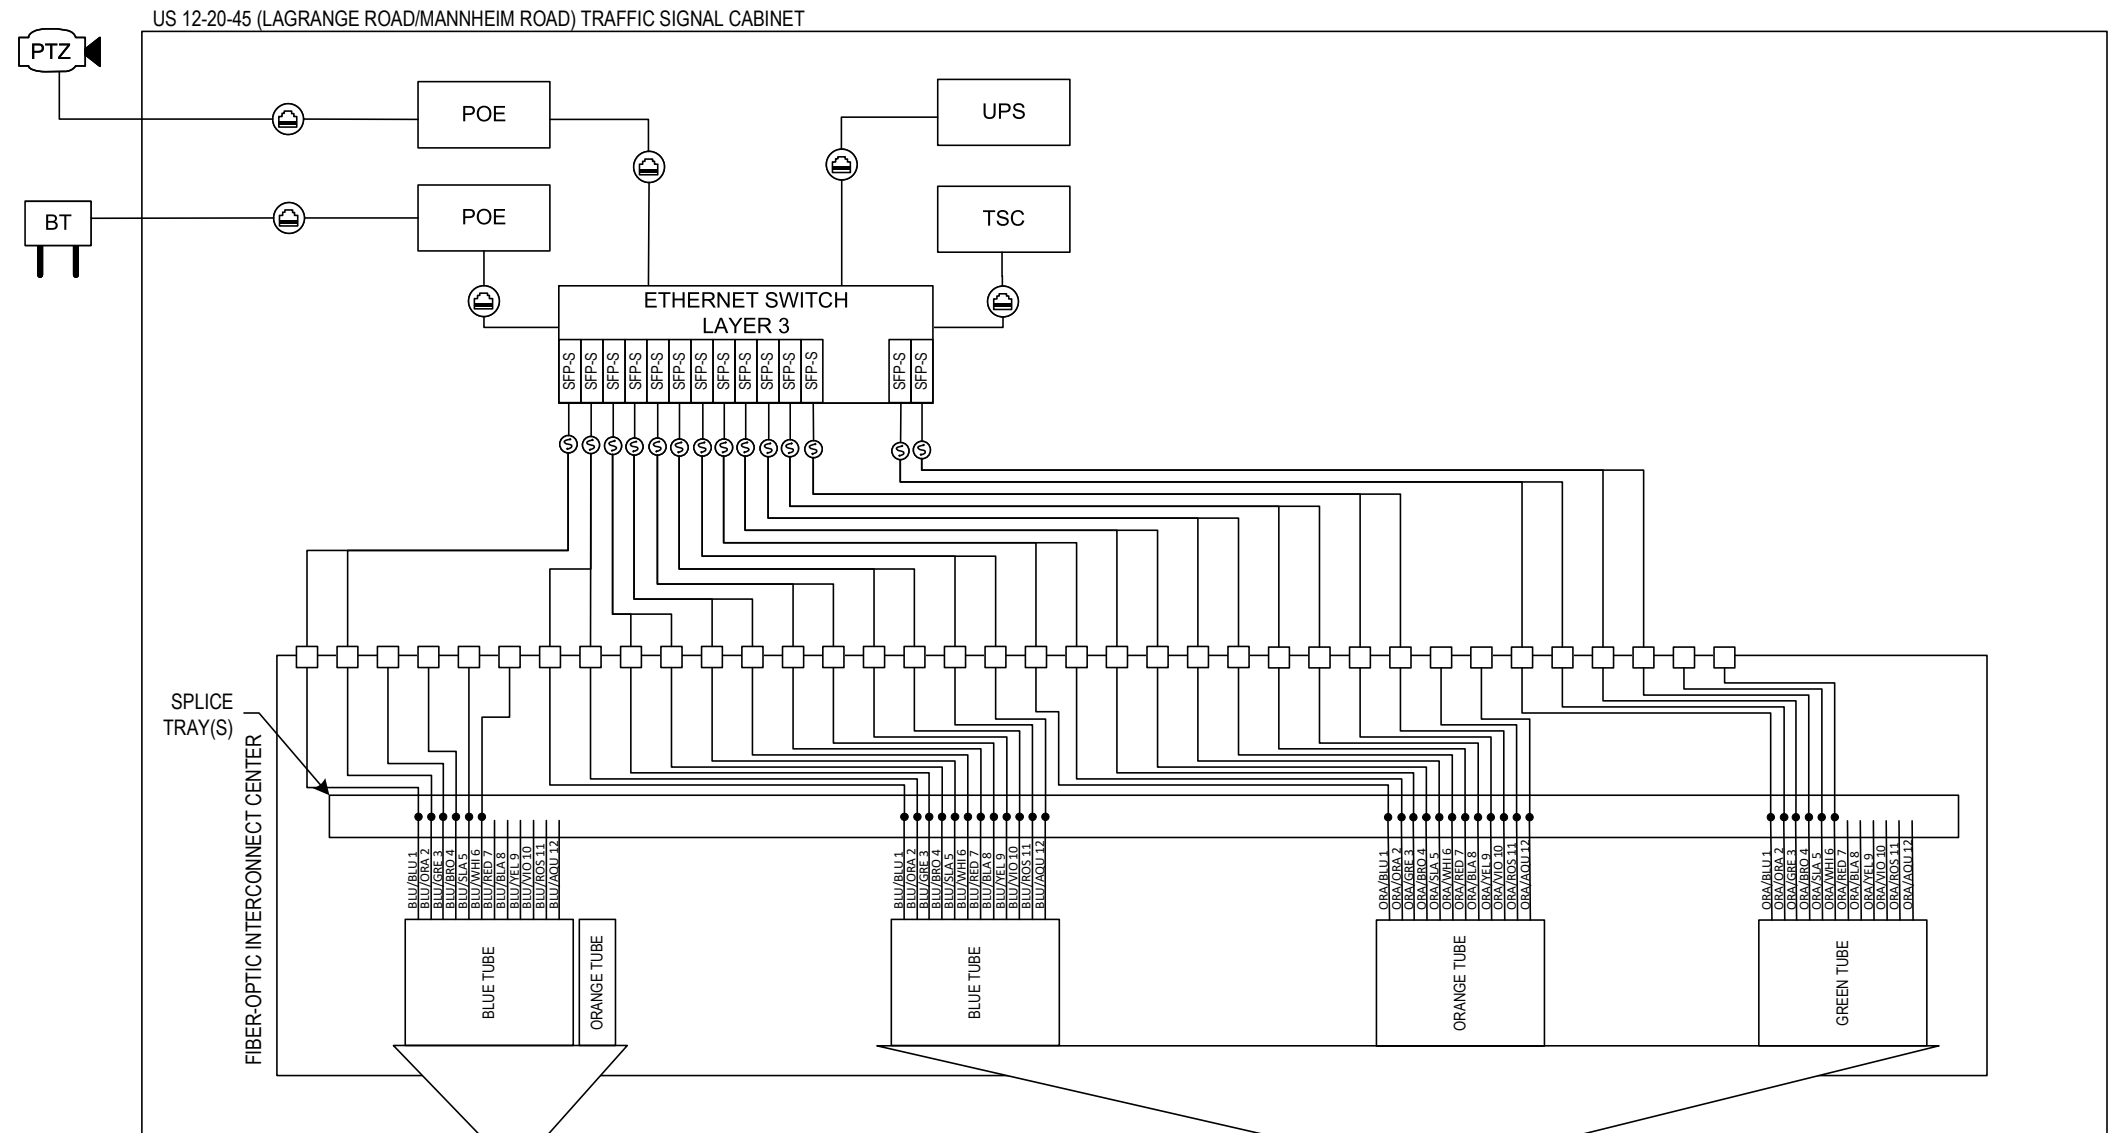

**LEGEND**

**PROPOSED**

- FIBER OPTIC CABLE (FOC)
- FIBER-OPTIC FUSION SPLICE
- FIBER PATCH PANEL PORT
- CAT 6 CABLE
- FIBER OPTIC PATCH CABLE, DUPLEX
- FIBER OPTIC TRANSCEIVER – SINGLE MODE
- BLUETOOTH DETECTOR
- TRAFFIC SIGNAL CONTROLLER
- CCTV CAMERA, PAN-TILT-ZOOM
- POWER OVER ETHERNET INJECTOR
- UNINTERRUPTIBLE POWER SUPPLY

FOC 24F SM  
(SIGNAL INTERCONNECT)

SEE NOTE 5

FOC 36F SM  
(LCF-IL56-007a)

COMM. VAULT (CMV-IL56-17C)

**NOTES:**

- DISTRIBUTION CABLE-FIBER (DCF) TUBES CONTAINING UNUSED FIBER STRANDS SHALL REMAIN UNCUT UNLESS OTHERWISE DIRECTED BY THE ENGINEER.
- TRUNK CABLE-FIBER (TCF) TUBES CONTAINING UNUSED FIBER STRANDS SHALL REMAIN UNCUT UNLESS OTHERWISE DIRECTED BY THE ENGINEER.
- UNSPLICED FIBER STRANDS SHALL BE COILED WITHIN SPLICE TRAY.
- FIBER-OPTIC CABLE DEPICTED IS GUIDANCE ONLY. ACTUAL FIBER-OPTIC CABLE FROM DMS CONTROLLER TO DMS DISPLAY SHALL BE IN ACCORDANCE WITH THE DMS MANUFACTURER'S REQUIREMENTS.
- REFER TO TRAFFIC SIGNAL PLANS AND INTERCONNECT SHEETS FOR ADDITIONAL INFORMATION.

ITS-51



DESIGNED - YJ  
DRAWN - MT  
CHECKED - RCB/KA  
DATE - 11-22-2024


REVISED -  
REVISED -  
REVISED -  
REVISED -


STATE OF ILLINOIS  
DEPARTMENT OF TRANSPORTATION

TRAFFIC SIGNAL FIBER SPLICING DIAGRAM (2 OF 2)  
CERMAK RD / 22ND ST. AND US 12-20-45 (LAGRANGE/MANNHEIM)

N.T.S. SHEET OF SHEETS STA. TO STA.

| F.A.P.<br>RTE.            | SECTION             | COUNTY      | TOTAL<br>SHEETS | SHEET<br>NO. |
|---------------------------|---------------------|-------------|-----------------|--------------|
| 365                       | 20-265-SUR, SW & TS | DUPAGE/COOK | 492             | 390          |
| CONTRACT NO. 62N39        |                     |             |                 |              |
| ILLINOIS FED. AID PROJECT |                     |             |                 |              |

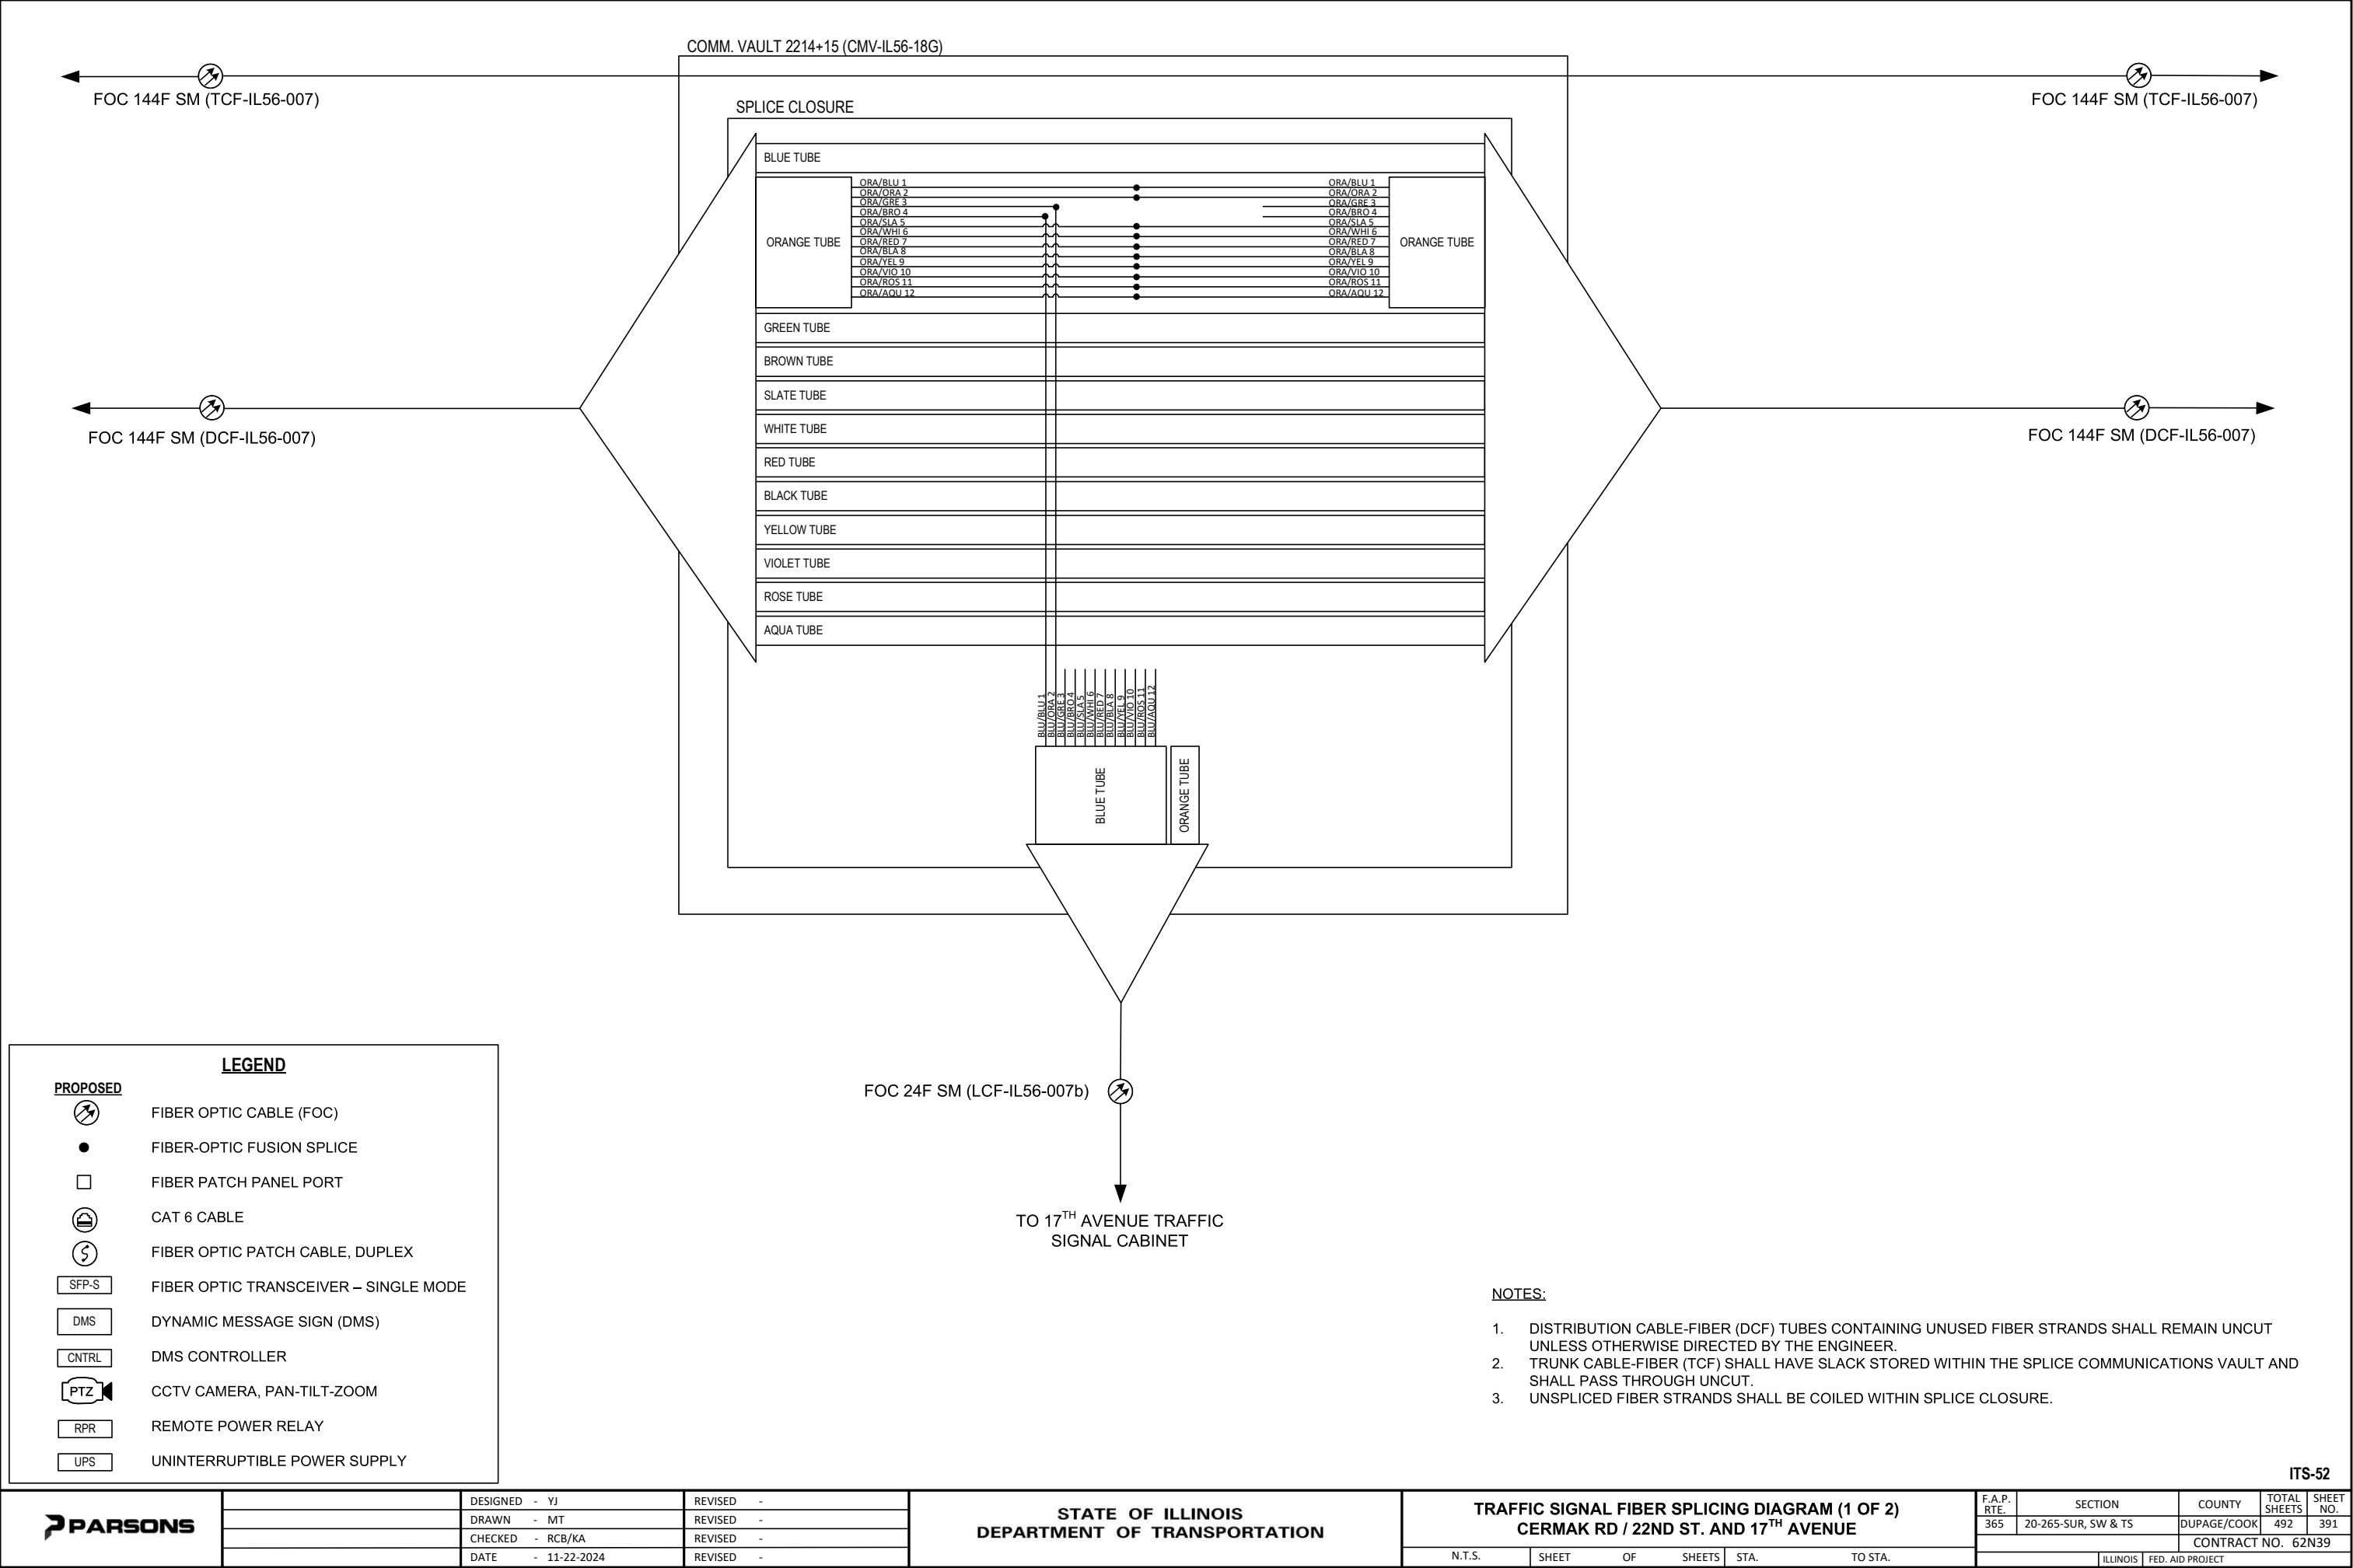

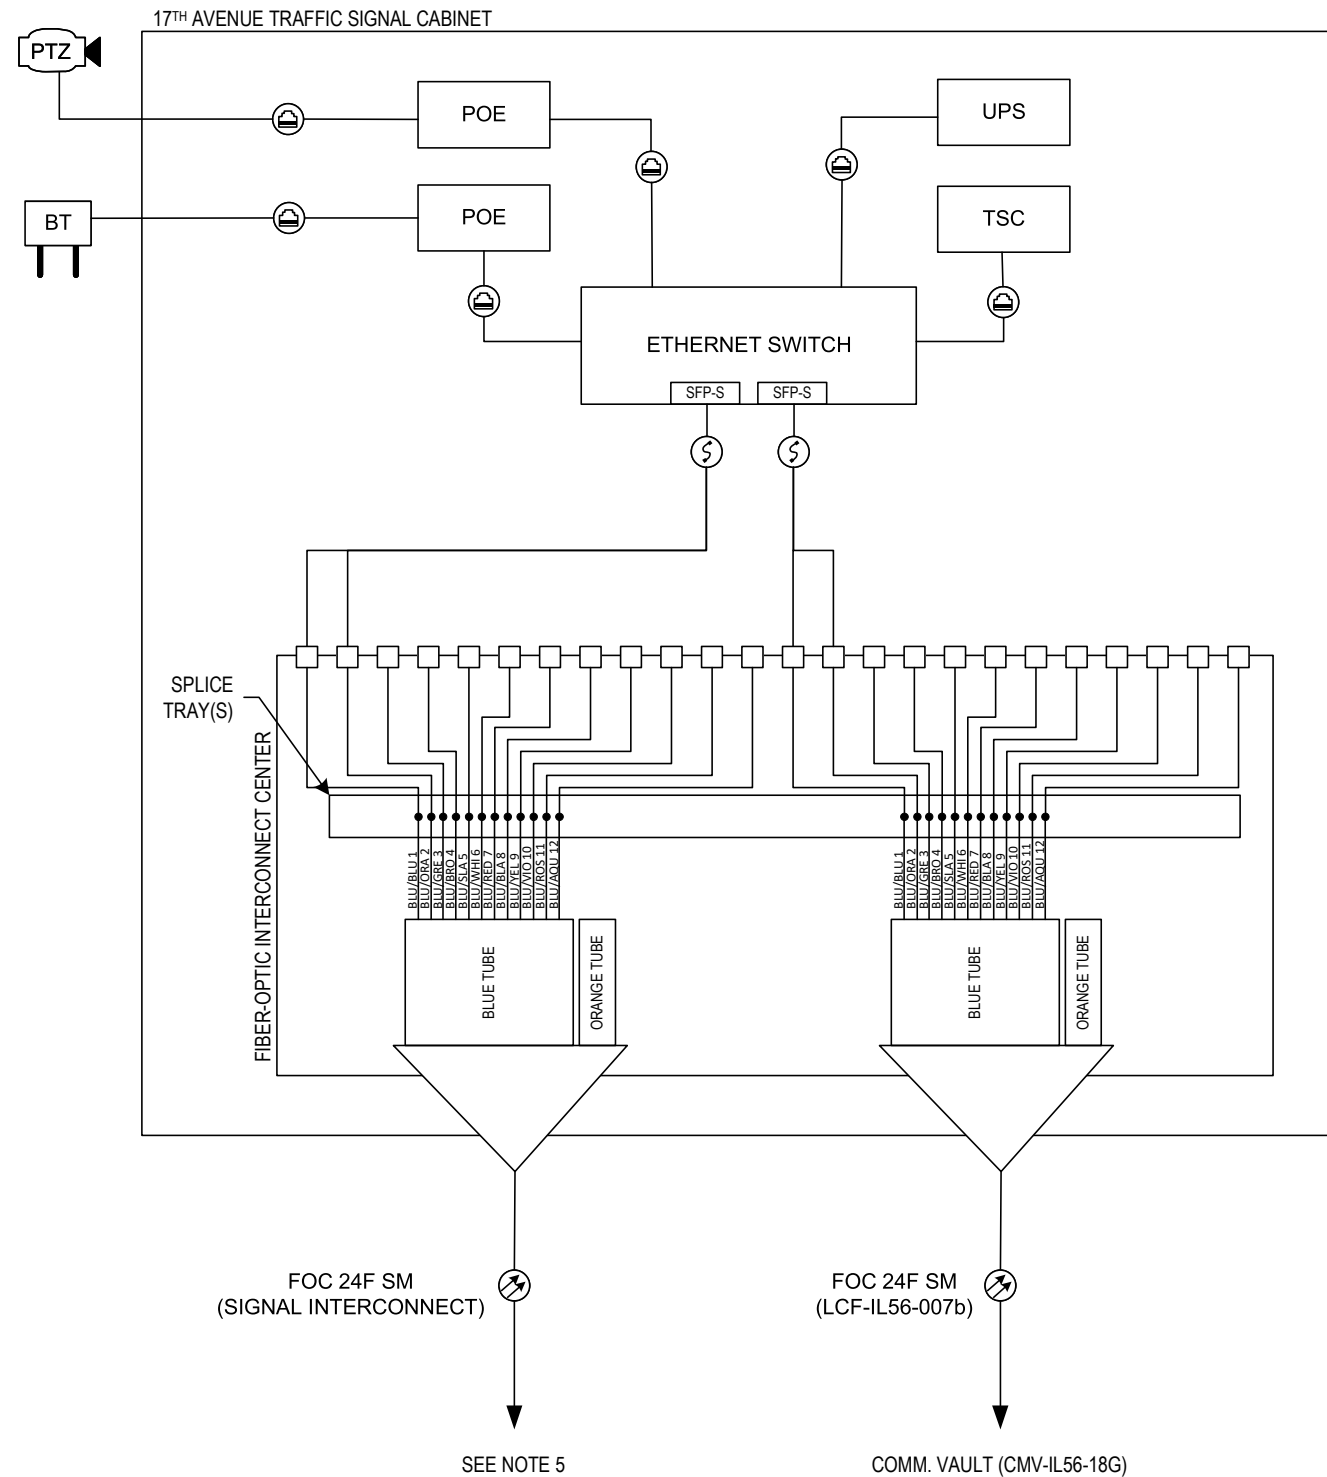

### LEGEND

#### PROPOSED

-  FIBER OPTIC CABLE (FOC)
-  FIBER-OPTIC FUSION SPLICE
-  FIBER PATCH PANEL PORT
-  CAT 6 CABLE
-  FIBER OPTIC PATCH CABLE, DUPLEX
-  FIBER OPTIC TRANSCEIVER – SINGLE MODE
-  BLUETOOTH DETECTOR
-  TRAFFIC SIGNAL CONTROLLER
-  CCTV CAMERA, PAN-TILT-ZOOM
-  POWER OVER ETHERNET INJECTOR
-  UNINTERRUPTIBLE POWER SUPPLY

#### NOTES:

- DISTRIBUTION CABLE-FIBER (DCF) TUBES CONTAINING UNUSED FIBER STRANDS SHALL REMAIN UNCUT UNLESS OTHERWISE DIRECTED BY THE ENGINEER.
- TRUNK CABLE-FIBER (TCF) SHALL HAVE SLACK STORED WITHIN THE SPLICE COMMUNICATIONS VAULT AND SHALL PASS THROUGH UNCUT.
- UNSPLICED FIBER STRANDS SHALL BE COILED WITHIN SPLICE TRAY.
- FIBER-OPTIC CABLE DEPICTED IS GUIDANCE ONLY. ACTUAL FIBER-OPTIC CABLE FROM DMS CONTROLLER TO DMS DISPLAY SHALL BE IN ACCORDANCE WITH THE DMS MANUFACTURER'S REQUIREMENTS.
- REFER TO TRAFFIC SIGNAL PLANS AND INTERCONNECT SHEETS FOR ADDITIONAL INFORMATION.

ITS-53



DESIGNED - YJ  
DRAWN - MT  
CHECKED - RCB/KA  
DATE - 11-22-2024

REVISED -  
REVISED -  
REVISED -  
REVISED -

STATE OF ILLINOIS  
DEPARTMENT OF TRANSPORTATION

TRAFFIC SIGNAL FIBER SPLICING DIAGRAM (2 OF 2)  
CERMAK RD / 22ND ST. AND 17TH AVENUE


N.T.S. SHEET OF SHEETS STA. TO STA.

| F.A.P. RTE.        | SECTION             | COUNTY           | TOTAL SHEETS | SHEET NO. |
|--------------------|---------------------|------------------|--------------|-----------|
| 365                | 20-265-SUR, SW & TS | DUPAGE/COOK      | 492          | 392       |
| CONTRACT NO. 62N39 |                     |                  |              |           |
| ILLINOIS           |                     | FED. AID PROJECT |              |           |





14TH AVENUE TRAFFIC SIGNAL CABINET

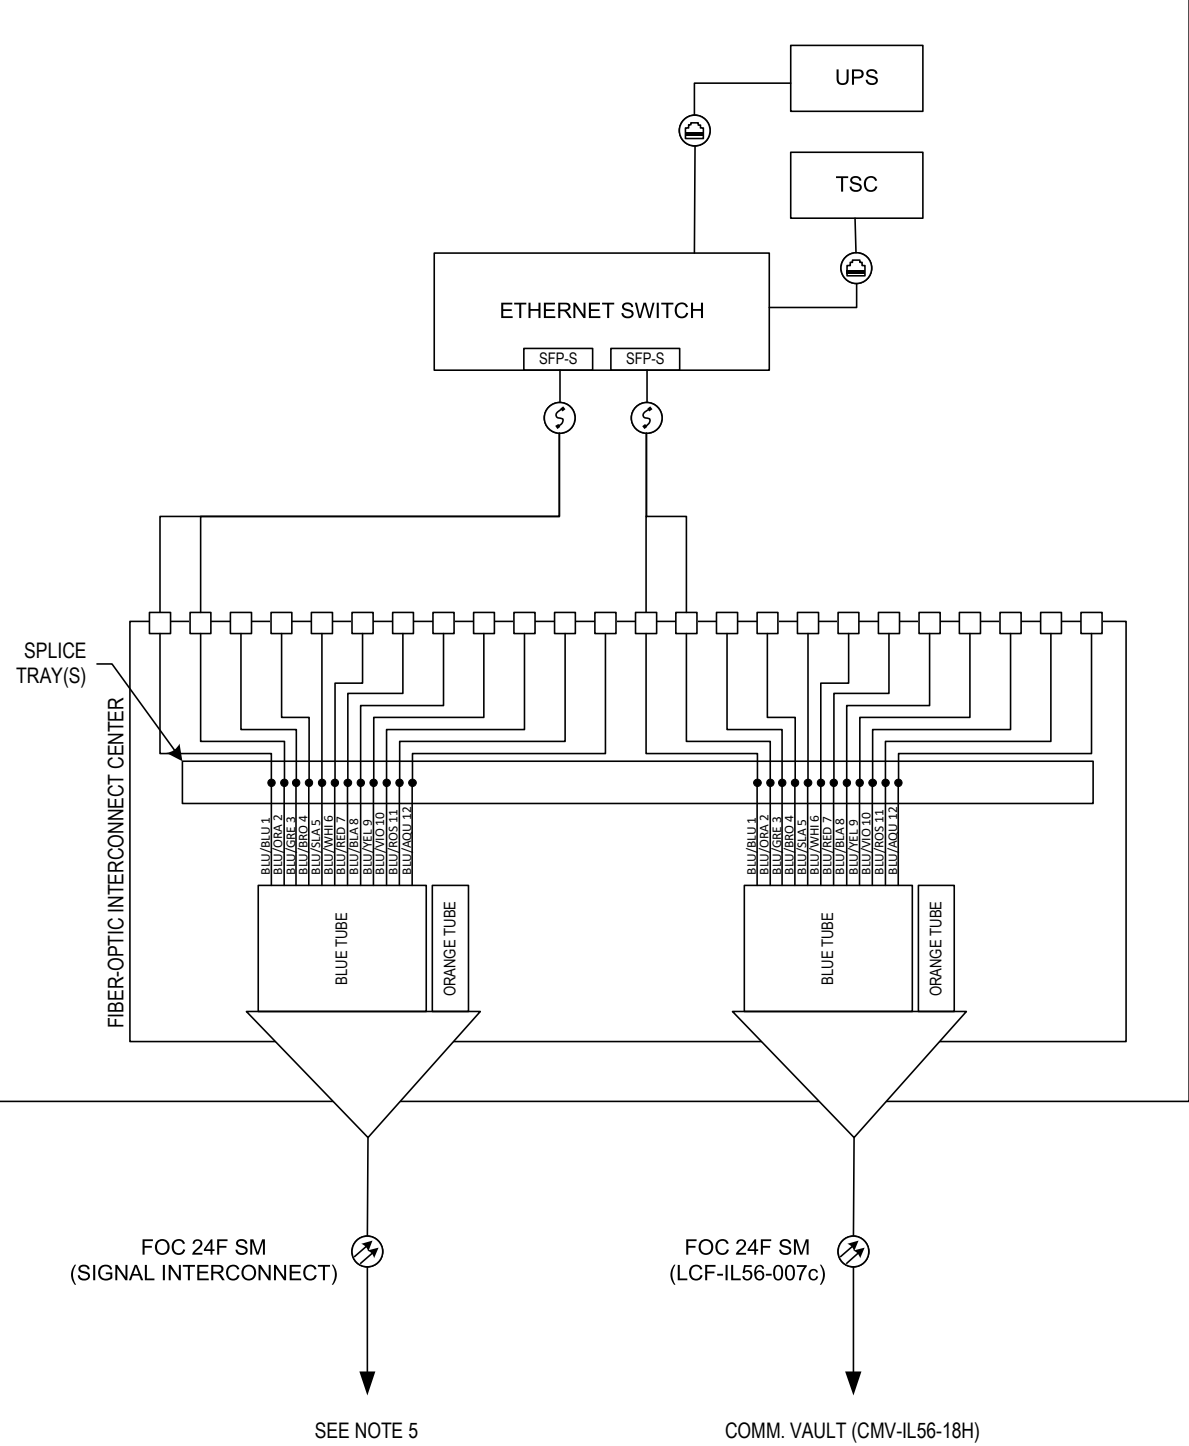

LEGEND

PROPOSED

- FIBER OPTIC CABLE (FOC)
- FIBER-OPTIC FUSION SPLICE
- FIBER PATCH PANEL PORT
- CAT 6 CABLE
- FIBER OPTIC PATCH CABLE, DUPLEX
- FIBER OPTIC TRANSCEIVER – SINGLE MODE
- BLUETOOTH DETECTOR
- TRAFFIC SIGNAL CONTROLLER
- CCTV CAMERA, PAN-TILT-ZOOM
- POWER OVER ETHERNET INJECTOR
- UNINTERRUPTIBLE POWER SUPPLY

NOTES:

- DISTRIBUTION CABLE-FIBER (DCF) TUBES CONTAINING UNUSED FIBER STRANDS SHALL REMAIN UNCUT UNLESS OTHERWISE DIRECTED BY THE ENGINEER.
- TRUNK CABLE-FIBER (TCF) SHALL HAVE SLACK STORED WITHIN THE SPLICE COMMUNICATIONS VAULT AND SHALL PASS THROUGH UNCUT.
- UNSPLICED FIBER STRANDS SHALL BE COILED WITHIN SPLICE TRAY.
- FIBER-OPTIC CABLE DEPICTED IS GUIDANCE ONLY. ACTUAL FIBER-OPTIC CABLE FROM DMS CONTROLLER TO DMS DISPLAY SHALL BE IN ACCORDANCE WITH THE DMS MANUFACTURER'S REQUIREMENTS.
- REFER TO TRAFFIC SIGNAL PLANS AND INTERCONNECT SHEETS FOR ADDITIONAL INFORMATION.

ITS-55



DESIGNED - YJ  
DRAWN - MT  
CHECKED - RCB/KA  
DATE - 11-22-2024


REVISED -  
REVISED -  
REVISED -  
REVISED -

STATE OF ILLINOIS  
DEPARTMENT OF TRANSPORTATION

TRAFFIC SIGNAL FIBER SPLICING DIAGRAM (2 OF 2)  
CERMAK RD / 22ND ST. AND 14TH AVENUE

N.T.S. SHEET OF SHEETS STA. TO STA.

| F.A.P. RTE.               | SECTION             | COUNTY      | TOTAL SHEETS | SHEET NO. |
|---------------------------|---------------------|-------------|--------------|-----------|
| 365                       | 20-265-SUR, SW & TS | DUPAGE/COOK | 492          | 394       |
| CONTRACT NO. 62N39        |                     |             |              |           |
| ILLINOIS FED. AID PROJECT |                     |             |              |           |

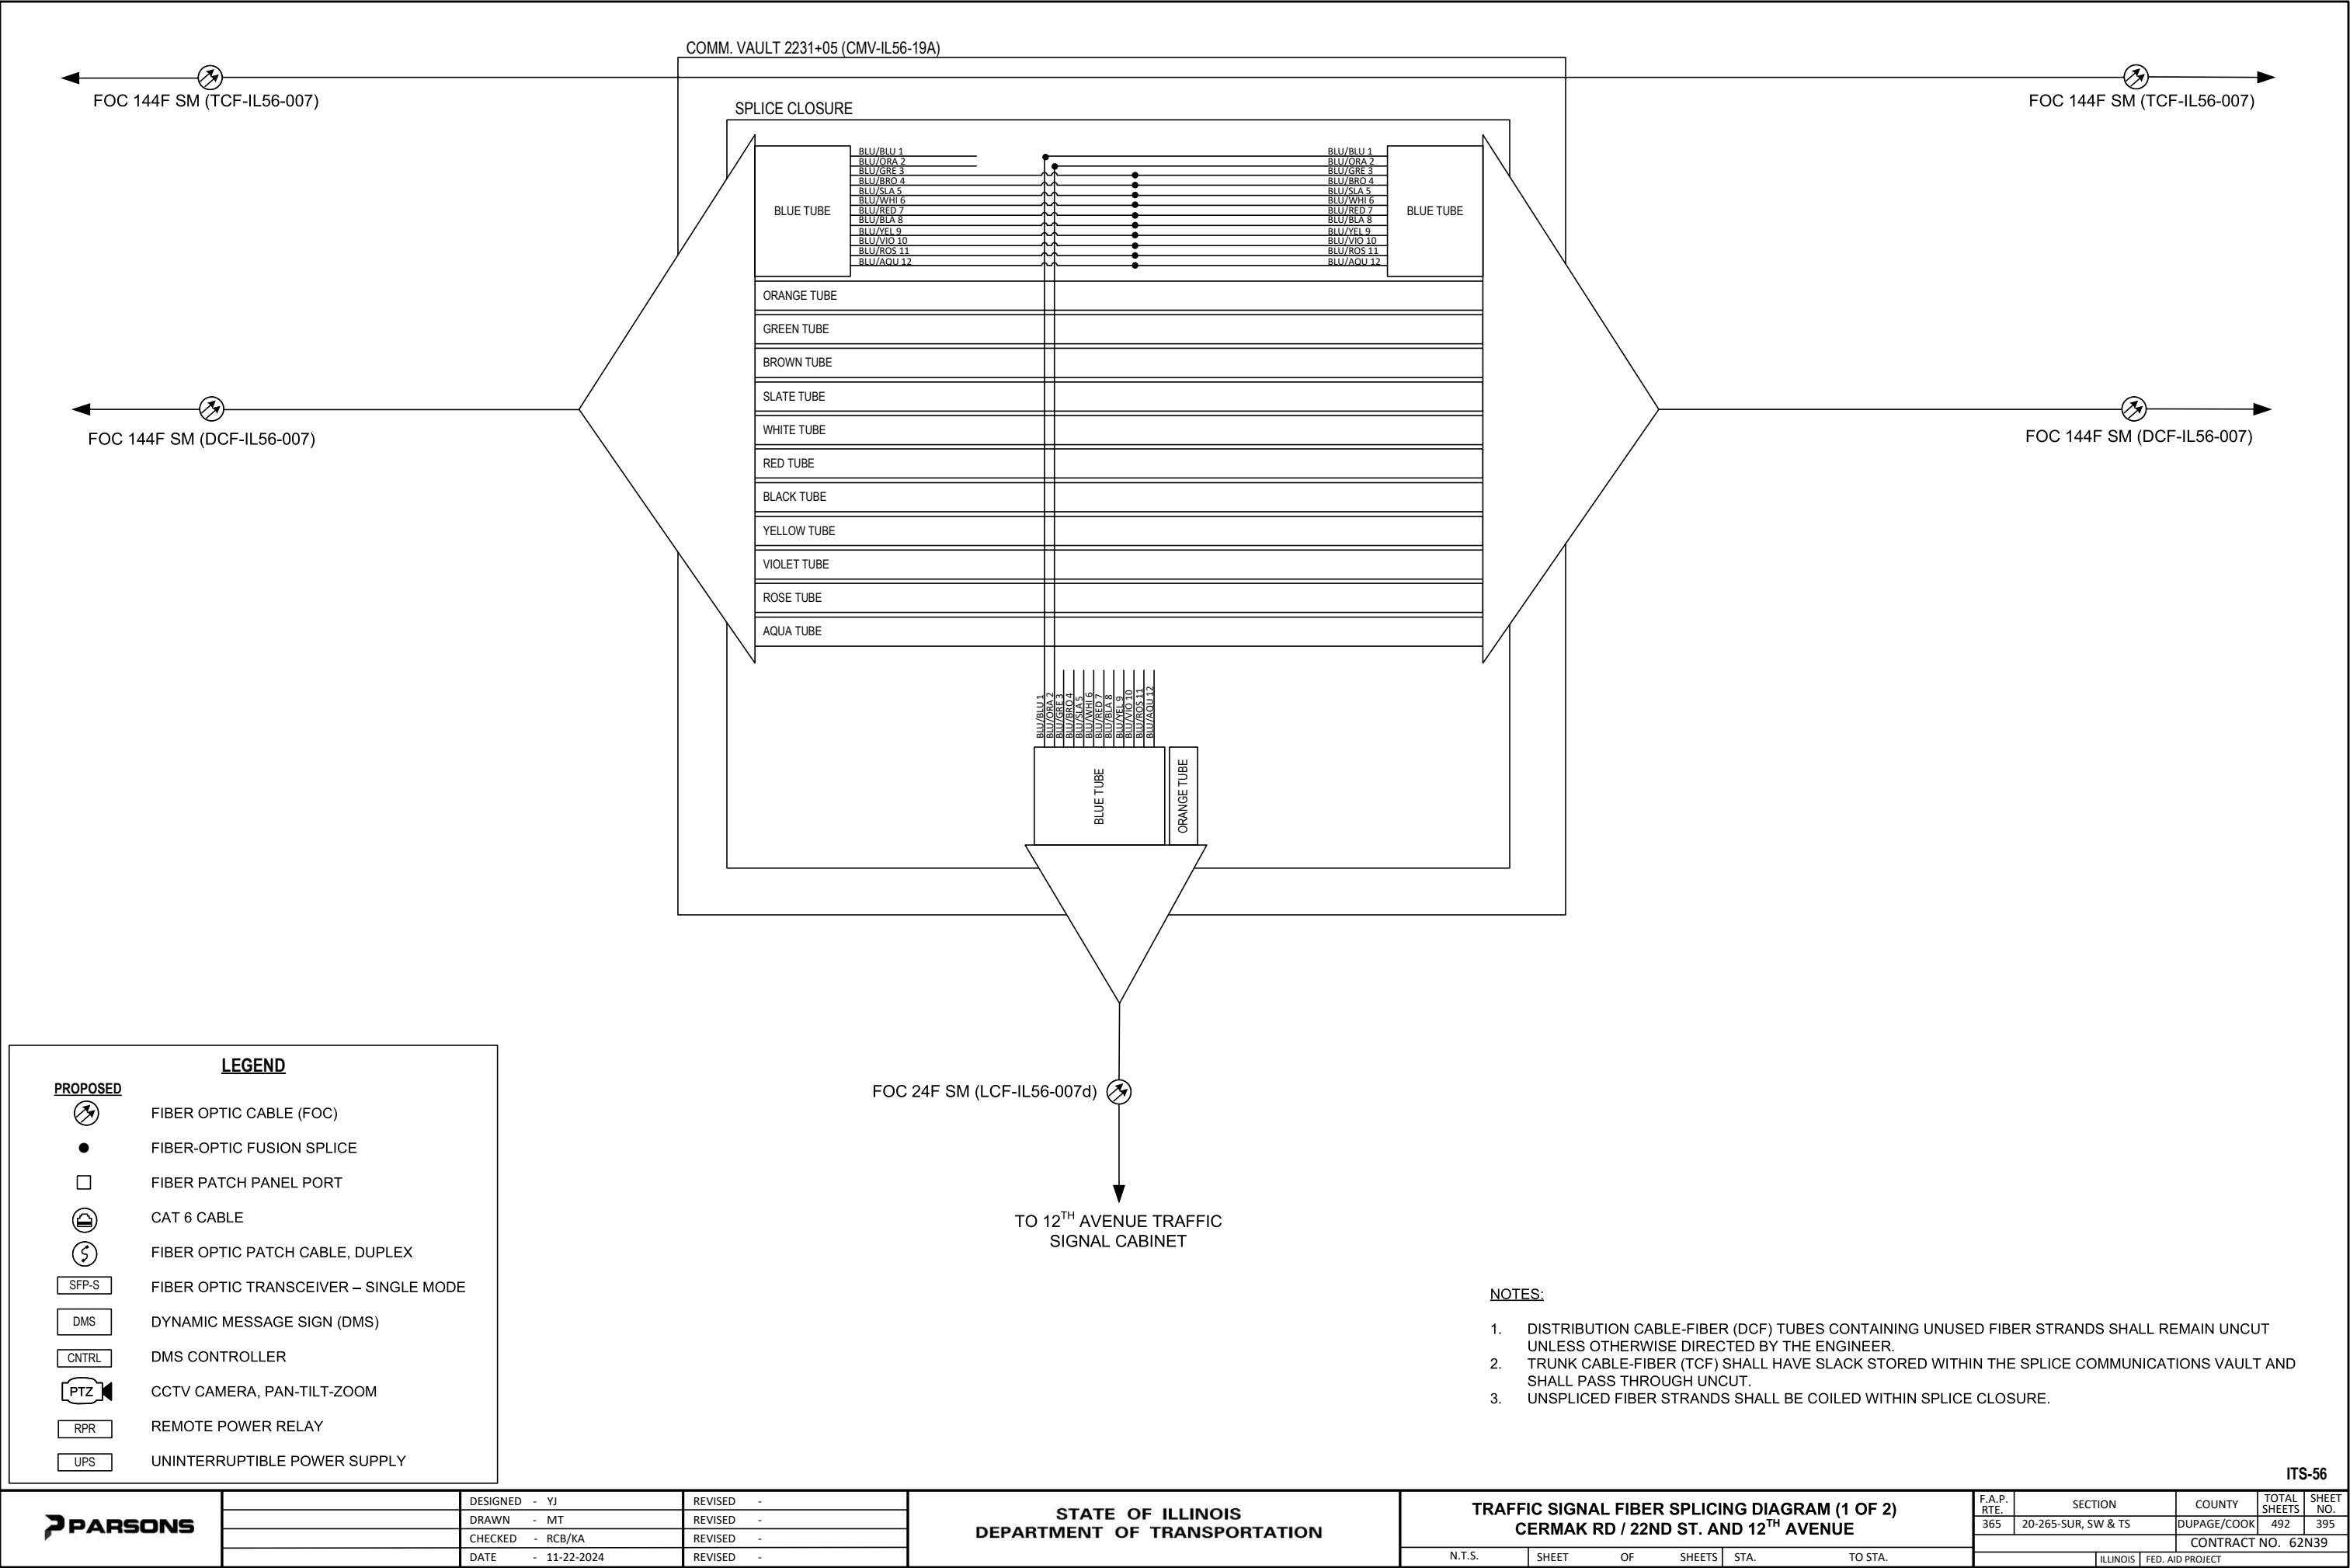

LEGEND

NOTES:

1. DISTRIBUTION CABLE-FIBER (DCF) TUBES CONTAINING UNUSED FIBER STRANDS SHALL REMAIN UNCUT UNLESS OTHERWISE DIRECTED BY THE ENGINEER.

2. TRUNK CABLE-FIBER (TCF) SHALL HAVE SLACK STORED WITHIN THE SPLICE COMMUNICATIONS VAULT AND SHALL PASS THROUGH UNCUT.

3. UNSPLICED FIBER STRANDS SHALL BE COILED WITHIN SPLICE CLOSURE.

PARSONS

DESIGNED - YJ

DRAWN - MT

CHECKED - RCB/KA

DATE - 11-22-2024

REVISED -

REVISED -

REVISED -

REVISED -

STATE OF ILLINOIS

DEPARTMENT OF TRANSPORTATION

TRAFFIC SIGNAL FIBER SPLICING DIAGRAM (1 OF 2)

CERMAK RD / 22ND ST. AND 12<sup>TH</sup> AVENUE

N.T.S.

SHEET

OF

SHEETS

STA.

TO STA.

F.A.P. RTE.

SECTION

COUNTY

TOTAL SHEETS

SHEET NO.

365

20-265-SUR, SW & TS

DUPAGE/COOK

492

395


CONTRACT NO. 62N39

ILLINOIS

FED. AID PROJECT

ITS-56



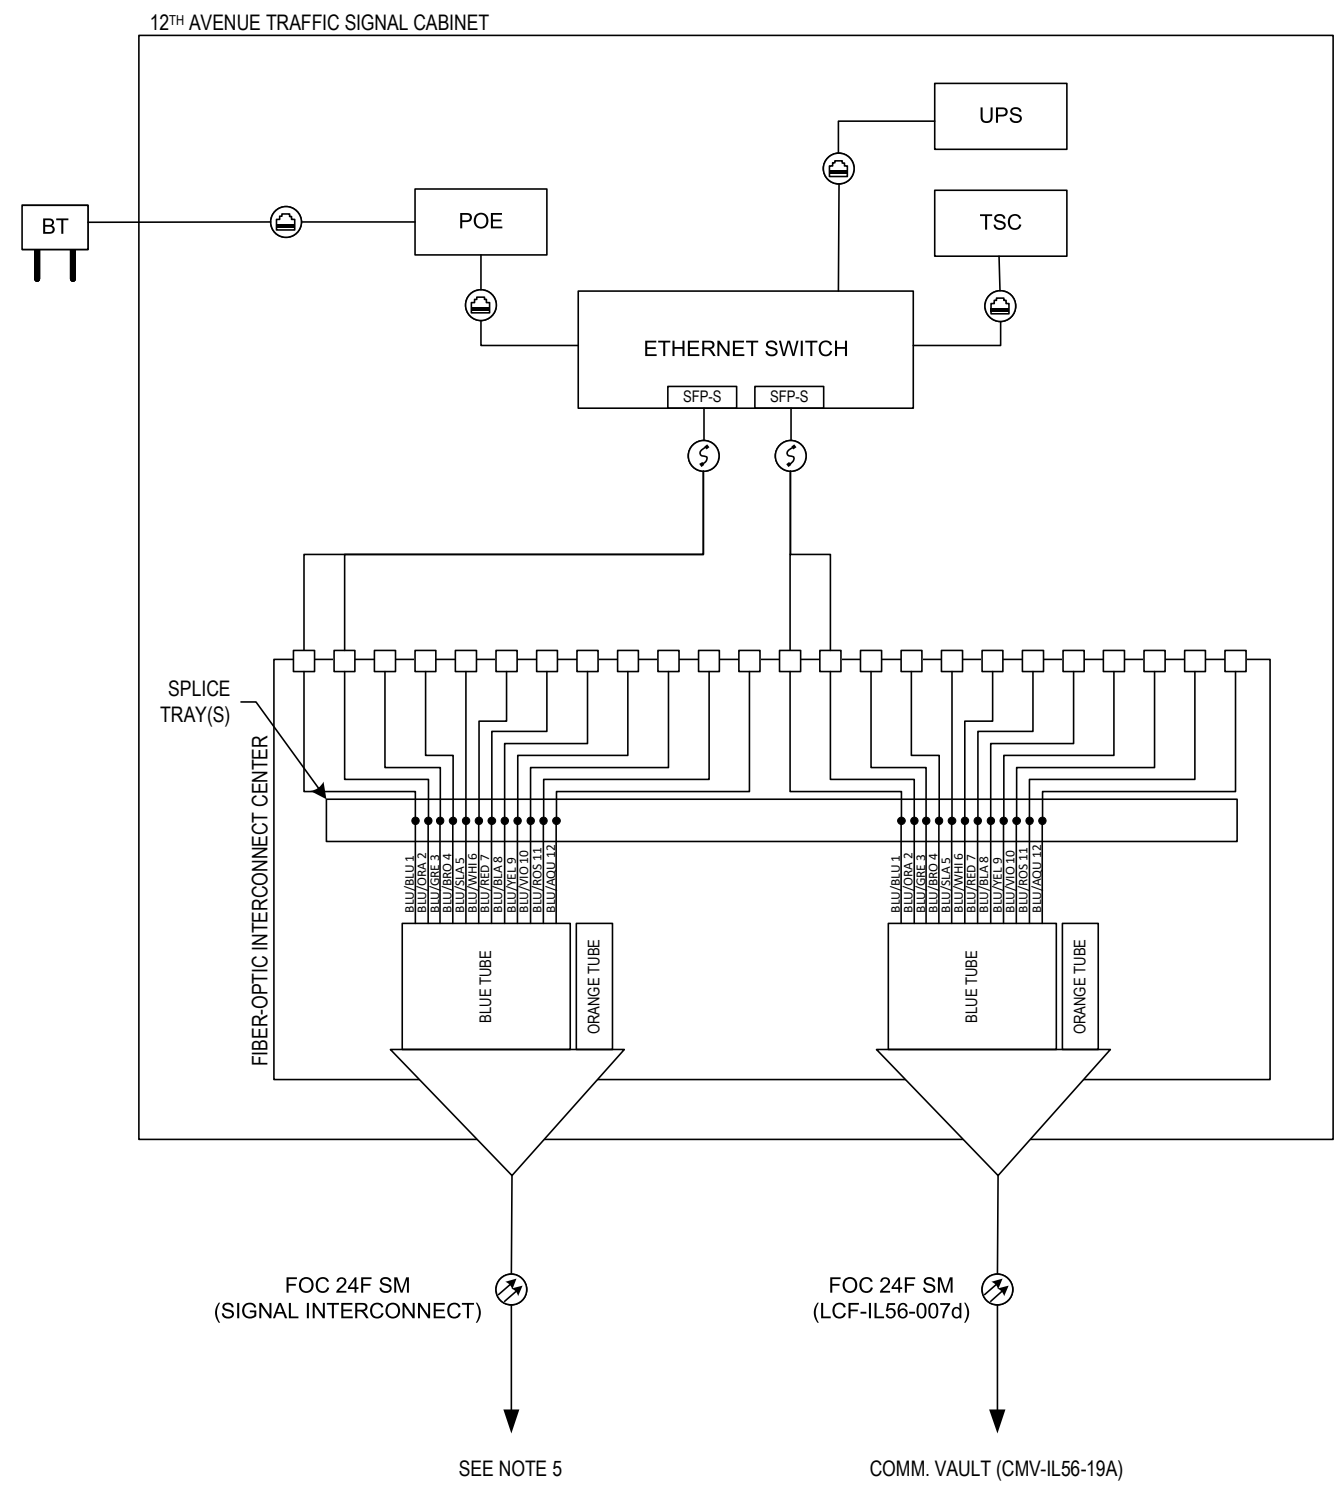

**LEGEND**

**PROPOSED**

- FIBER OPTIC CABLE (FOC)
- FIBER-OPTIC FUSION SPLICE
- FIBER PATCH PANEL PORT
- CAT 6 CABLE
- FIBER OPTIC PATCH CABLE, DUPLEX
- FIBER OPTIC TRANSCEIVER – SINGLE MODE
- BLUETOOTH DETECTOR
- TRAFFIC SIGNAL CONTROLLER
- CCTV CAMERA, PAN-TILT-ZOOM
- POWER OVER ETHERNET INJECTOR
- UNINTERRUPTIBLE POWER SUPPLY

**NOTES:**

- DISTRIBUTION CABLE-FIBER (DCF) TUBES CONTAINING UNUSED FIBER STRANDS SHALL REMAIN UNCUT UNLESS OTHERWISE DIRECTED BY THE ENGINEER.
- TRUNK CABLE-FIBER (TCF) SHALL HAVE SLACK STORED WITHIN THE SPLICE COMMUNICATIONS VAULT AND SHALL PASS THROUGH UNCUT.
- UNSPLICED FIBER STRANDS SHALL BE COILED WITHIN SPLICE TRAY.
- FIBER-OPTIC CABLE DEPICTED IS GUIDANCE ONLY. ACTUAL FIBER-OPTIC CABLE FROM DMS CONTROLLER TO DMS DISPLAY SHALL BE IN ACCORDANCE WITH THE DMS MANUFACTURER'S REQUIREMENTS.
- REFER TO TRAFFIC SIGNAL PLANS AND INTERCONNECT SHEETS FOR ADDITIONAL INFORMATION.

ITS-57



DESIGNED - YJ  
DRAWN - MT  
CHECKED - RCB/KA  
DATE - 11-22-2024

REVISED -  
REVISED -  
REVISED -  
REVISED -


STATE OF ILLINOIS  
DEPARTMENT OF TRANSPORTATION

TRAFFIC SIGNAL FIBER SPLICING DIAGRAM (2 OF 2)  
CERMAK RD / 22ND ST. AND 12TH AVENUE

N.T.S. SHEET OF SHEETS STA. TO STA.

| F.A.P. RTE.               | SECTION             | COUNTY      | TOTAL SHEETS | SHEET NO. |
|---------------------------|---------------------|-------------|--------------|-----------|
| 365                       | 20-265-SUR, SW & TS | DUPAGE/COOK | 492          | 396       |
| CONTRACT NO. 62N39        |                     |             |              |           |
| ILLINOIS FED. AID PROJECT |                     |             |              |           |

SPLICE CLOSURE

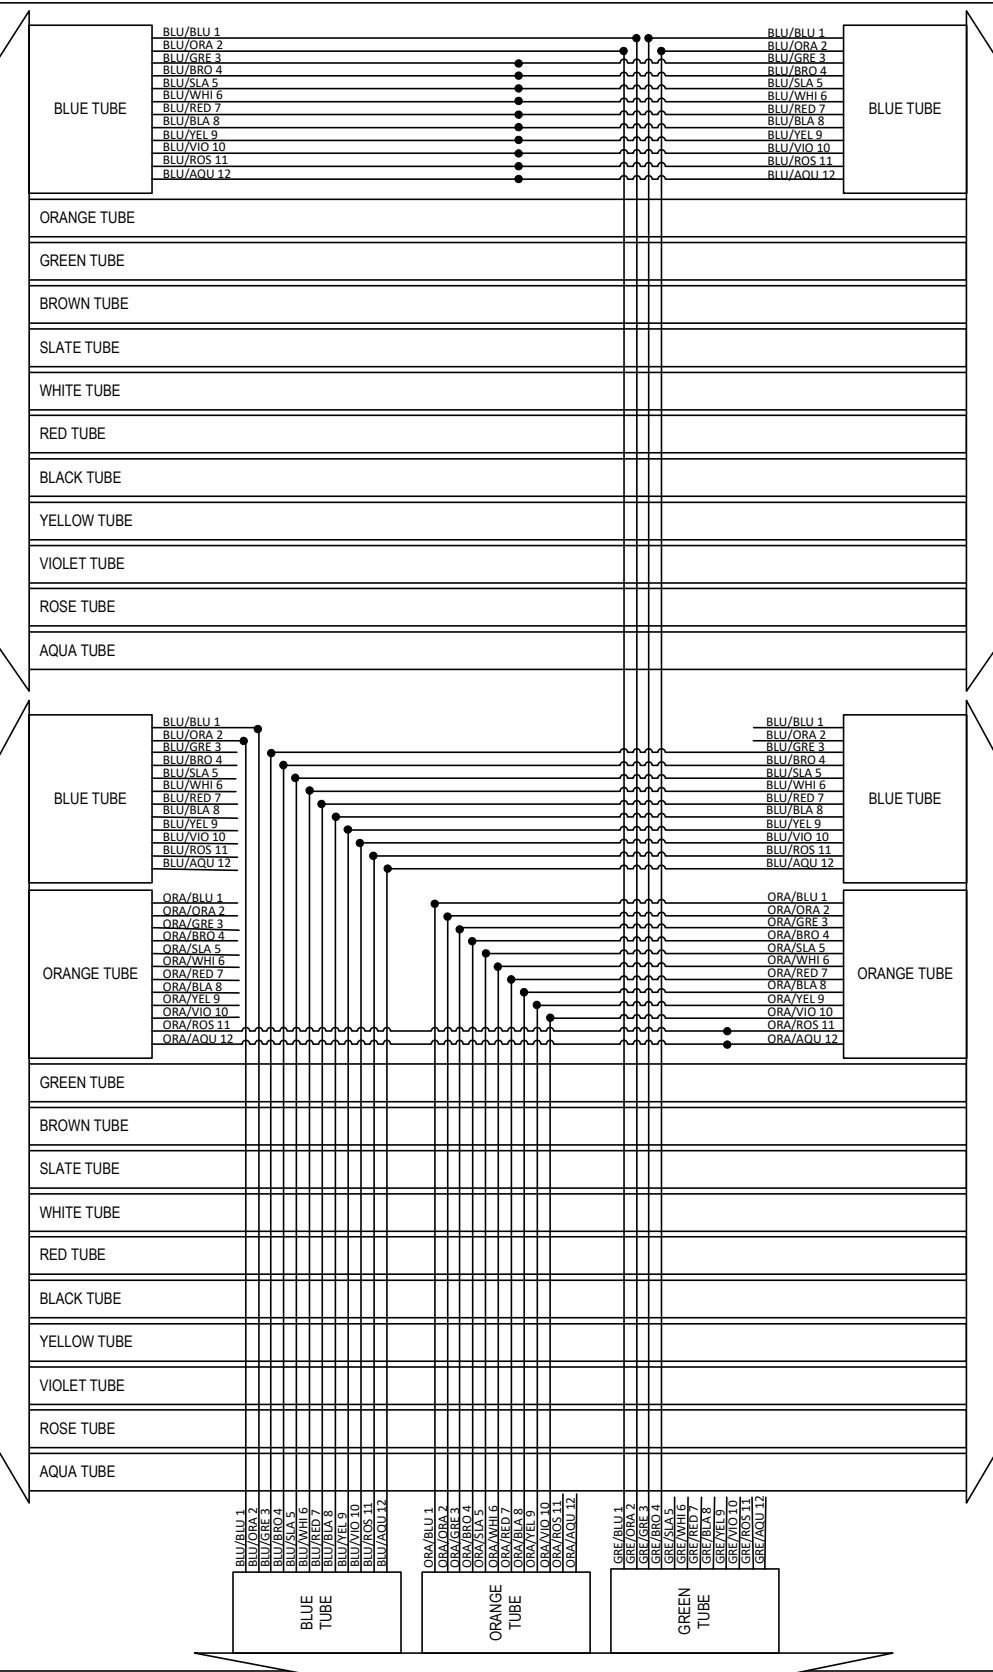

FOC 144F SM (TCF-IL56-007)

FOC 144F SM (TCF-IL56-008)

FOC 144F SM (DCF-IL56-007)

FOC 144F SM (DCF-IL56-008)

FOC 36F SM (LCF-IL56-008a)

TO 1<sup>ST</sup> AVENUE (IL 171) TRAFFIC SIGNAL CABINET

- NOTES:
- 1. DISTRIBUTION CABLE-FIBER (DCF) TUBES CONTAINING UNUSED FIBER STRANDS SHALL REMAIN UN CUT UNLESS OTHERWISE DIRECTED BY THE ENGINEER.
  - 2. TRUNK CABLE-FIBER (TCF) TUBES CONTAINING UNUSED FIBER STRANDS SHALL REMAIN UN CUT UNLESS OTHERWISE DIRECTED BY THE ENGINEER.
  - 3. UNSPLICED FIBER STRANDS SHALL BE COILED WITHIN SPLICE CLOSURE.

**PROPOSED**

FIBER OPTIC CABLE (FOC)

FIBER-OPTIC FUSION SPLICE

FIBER PATCH PANEL PORT

CAT 6 CABLE

FIBER OPTIC PATCH CABLE, DUPLEX

FIBER OPTIC TRANSCEIVER – SINGLE MODE

DYNAMIC MESSAGE SIGN (DMS)


DMS CONTROLLER


CCTV CAMERA, PAN-TILT-ZOOM

REMOTE POWER RELAY

UNINTERRUPTIBLE POWER SUPPLY



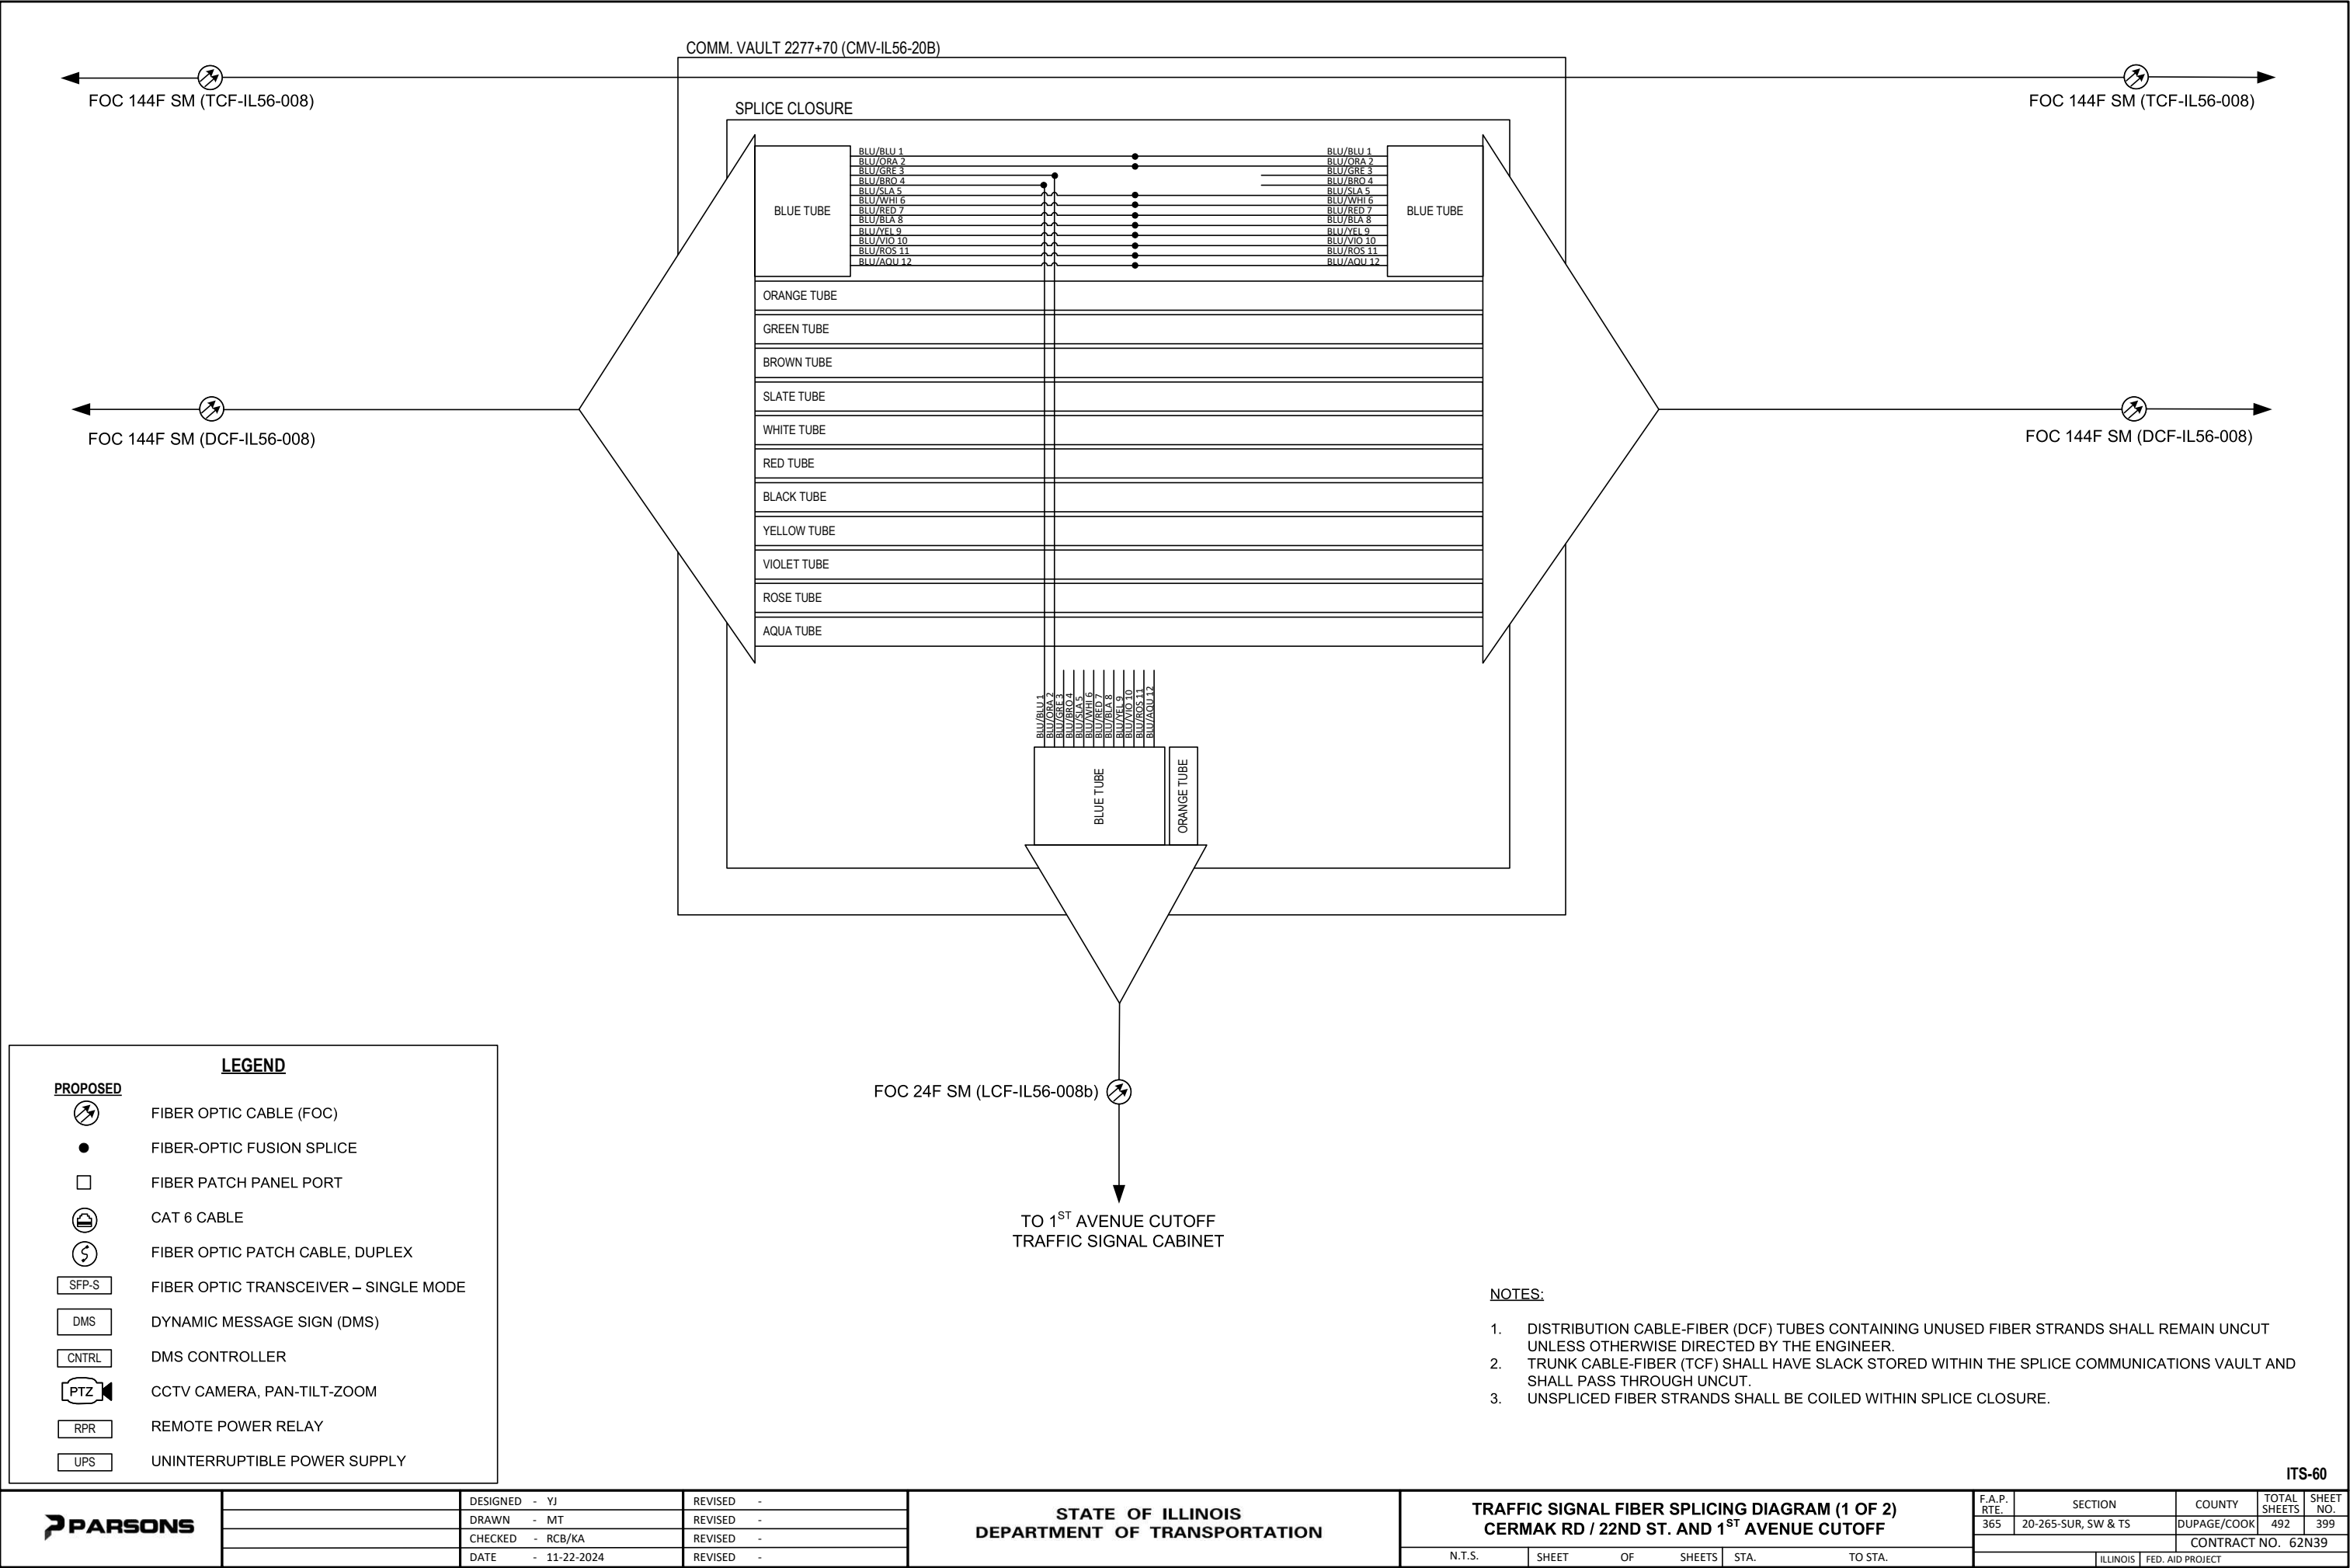

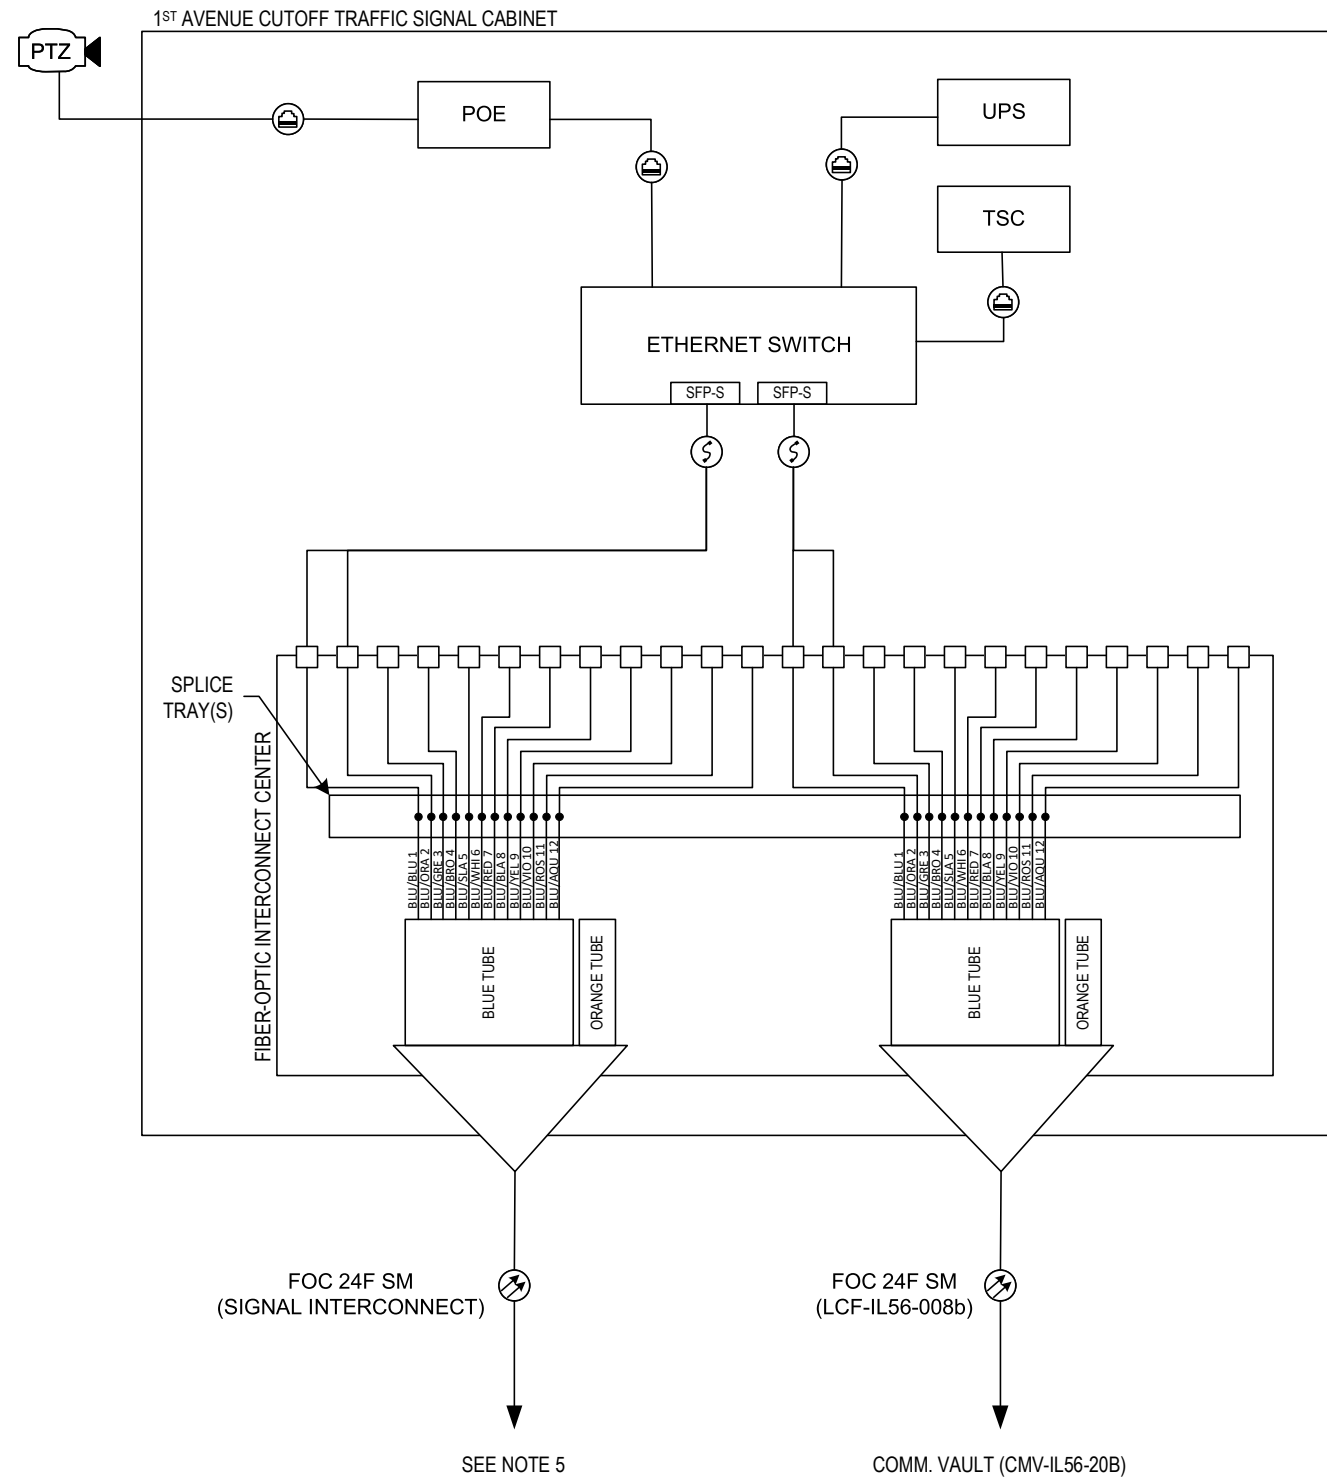

### LEGEND

#### PROPOSED

- FIBER OPTIC CABLE (FOC)
- FIBER-OPTIC FUSION SPLICE
- FIBER PATCH PANEL PORT
- CAT 6 CABLE
- FIBER OPTIC PATCH CABLE, DUPLEX
- FIBER OPTIC TRANSCEIVER – SINGLE MODE
- BLUETOOTH DETECTOR
- TRAFFIC SIGNAL CONTROLLER
- CCTV CAMERA, PAN-TILT-ZOOM
- POWER OVER ETHERNET INJECTOR
- UNINTERRUPTIBLE POWER SUPPLY

#### NOTES:

- DISTRIBUTION CABLE-FIBER (DCF) TUBES CONTAINING UNUSED FIBER STRANDS SHALL REMAIN UNCUT UNLESS OTHERWISE DIRECTED BY THE ENGINEER.
- TRUNK CABLE-FIBER (TCF) SHALL HAVE SLACK STORED WITHIN THE SPLICE COMMUNICATIONS VAULT AND SHALL PASS THROUGH UNCUT.
- UNSPLICED FIBER STRANDS SHALL BE COILED WITHIN SPLICE TRAY.
- FIBER-OPTIC CABLE DEPICTED IS GUIDANCE ONLY. ACTUAL FIBER-OPTIC CABLE FROM DMS CONTROLLER TO DMS DISPLAY SHALL BE IN ACCORDANCE WITH THE DMS MANUFACTURER'S REQUIREMENTS.
- REFER TO TRAFFIC SIGNAL PLANS AND INTERCONNECT SHEETS FOR ADDITIONAL INFORMATION.

ITS-61



DESIGNED - YJ  
DRAWN - MT  
CHECKED - RCB/KA  
DATE - 11-22-2024

REVISED -  
REVISED -  
REVISED -  
REVISED -

STATE OF ILLINOIS  
DEPARTMENT OF TRANSPORTATION

TRAFFIC SIGNAL FIBER SPLICING DIAGRAM (2 OF 2)  
CERMAK RD / 22ND ST. AND 1ST AVENUE CUTOFF

N.T.S. SHEET OF SHEETS STA. TO STA.

| F.A.P. RTE.               | SECTION             | COUNTY      | TOTAL SHEETS | SHEET NO. |
|---------------------------|---------------------|-------------|--------------|-----------|
| 365                       | 20-265-SUR, SW & TS | DUPAGE/COOK | 492          | 400       |
| CONTRACT NO. 62N39        |                     |             |              |           |
| ILLINOIS FED. AID PROJECT |                     |             |              |           |