



TYPICAL SPLICE DETAIL

N.T.S.

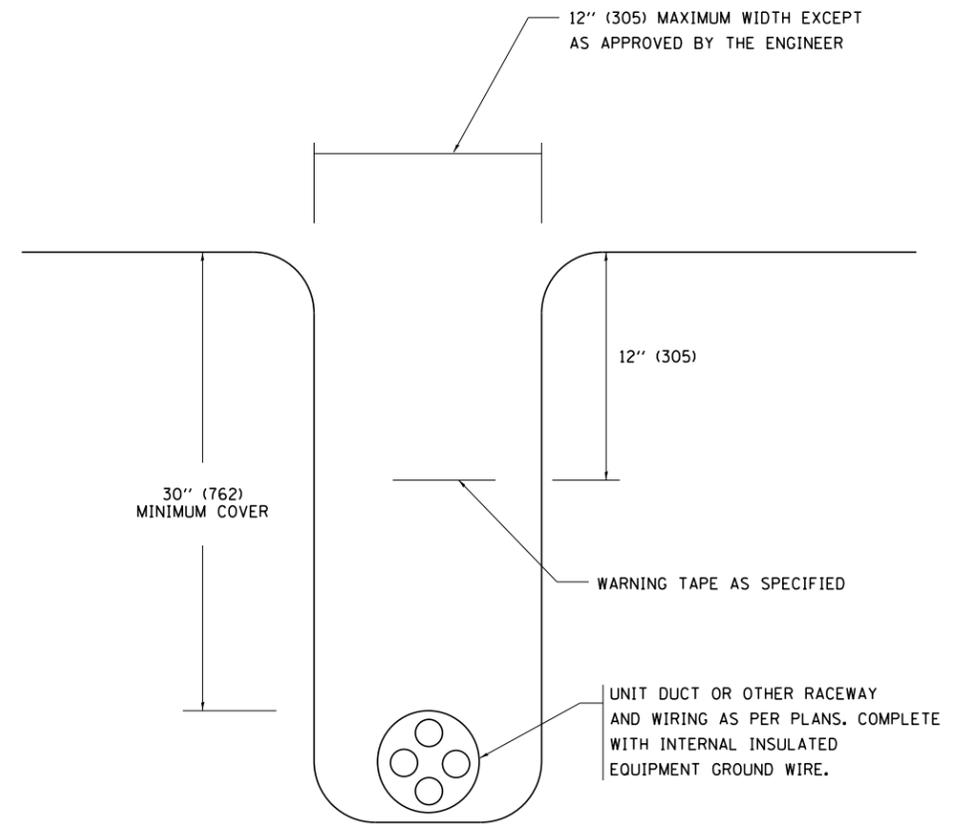

TYPICAL WIRING IN TRENCH DETAIL

N.T.S.

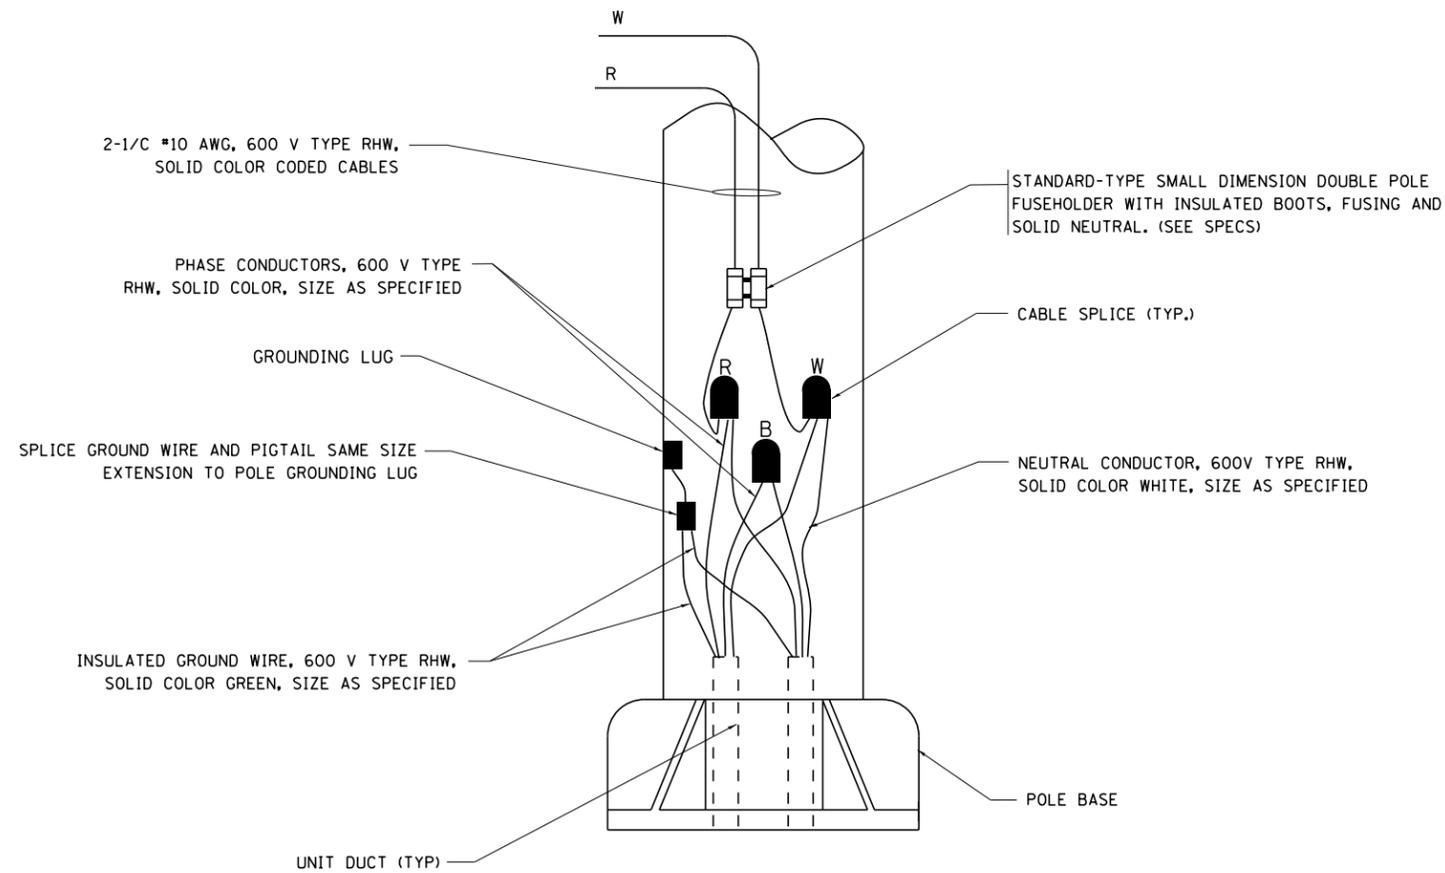

POLE WIRING DETAIL

N.T.S.

FILE NAME =	USER NAME = mgarvido	DESIGNED -	REVISED - 08-08-03
J:\13003\DN\CADD Sheets\11571-sht-light-06.dgn		DRAWN -	REVISED -
PLOT SCALE = 100.000000:1.000000		CHECKED -	REVISED -
PLOT DATE = 24-OCT-2013 13:06		DATE -	REVISED -

**STATE OF ILLINOIS
DEPARTMENT OF TRANSPORTATION**

MISC. ELECTRICAL DETAILS			
SHEET A			
SCALE: NONE	SHEET NO. 1 OF 1 SHEETS	STA.	TO STA.

F.A.P. RTE.	SECTION	COUNTY	TOTAL SHEETS	SHEET NO.
307	131B-BR	DUPAGE	111	41
BE-702		CONTRACT NO. 60V24		
FED. ROAD DIST. NO. 1 ILLINOIS FED. AID PROJECT				