



c:\pwworking\aecom\00\bw\itort\d0220246\DI60W29-sht-Light-07.dgn  
 10/28/2013 9:06:23 PM

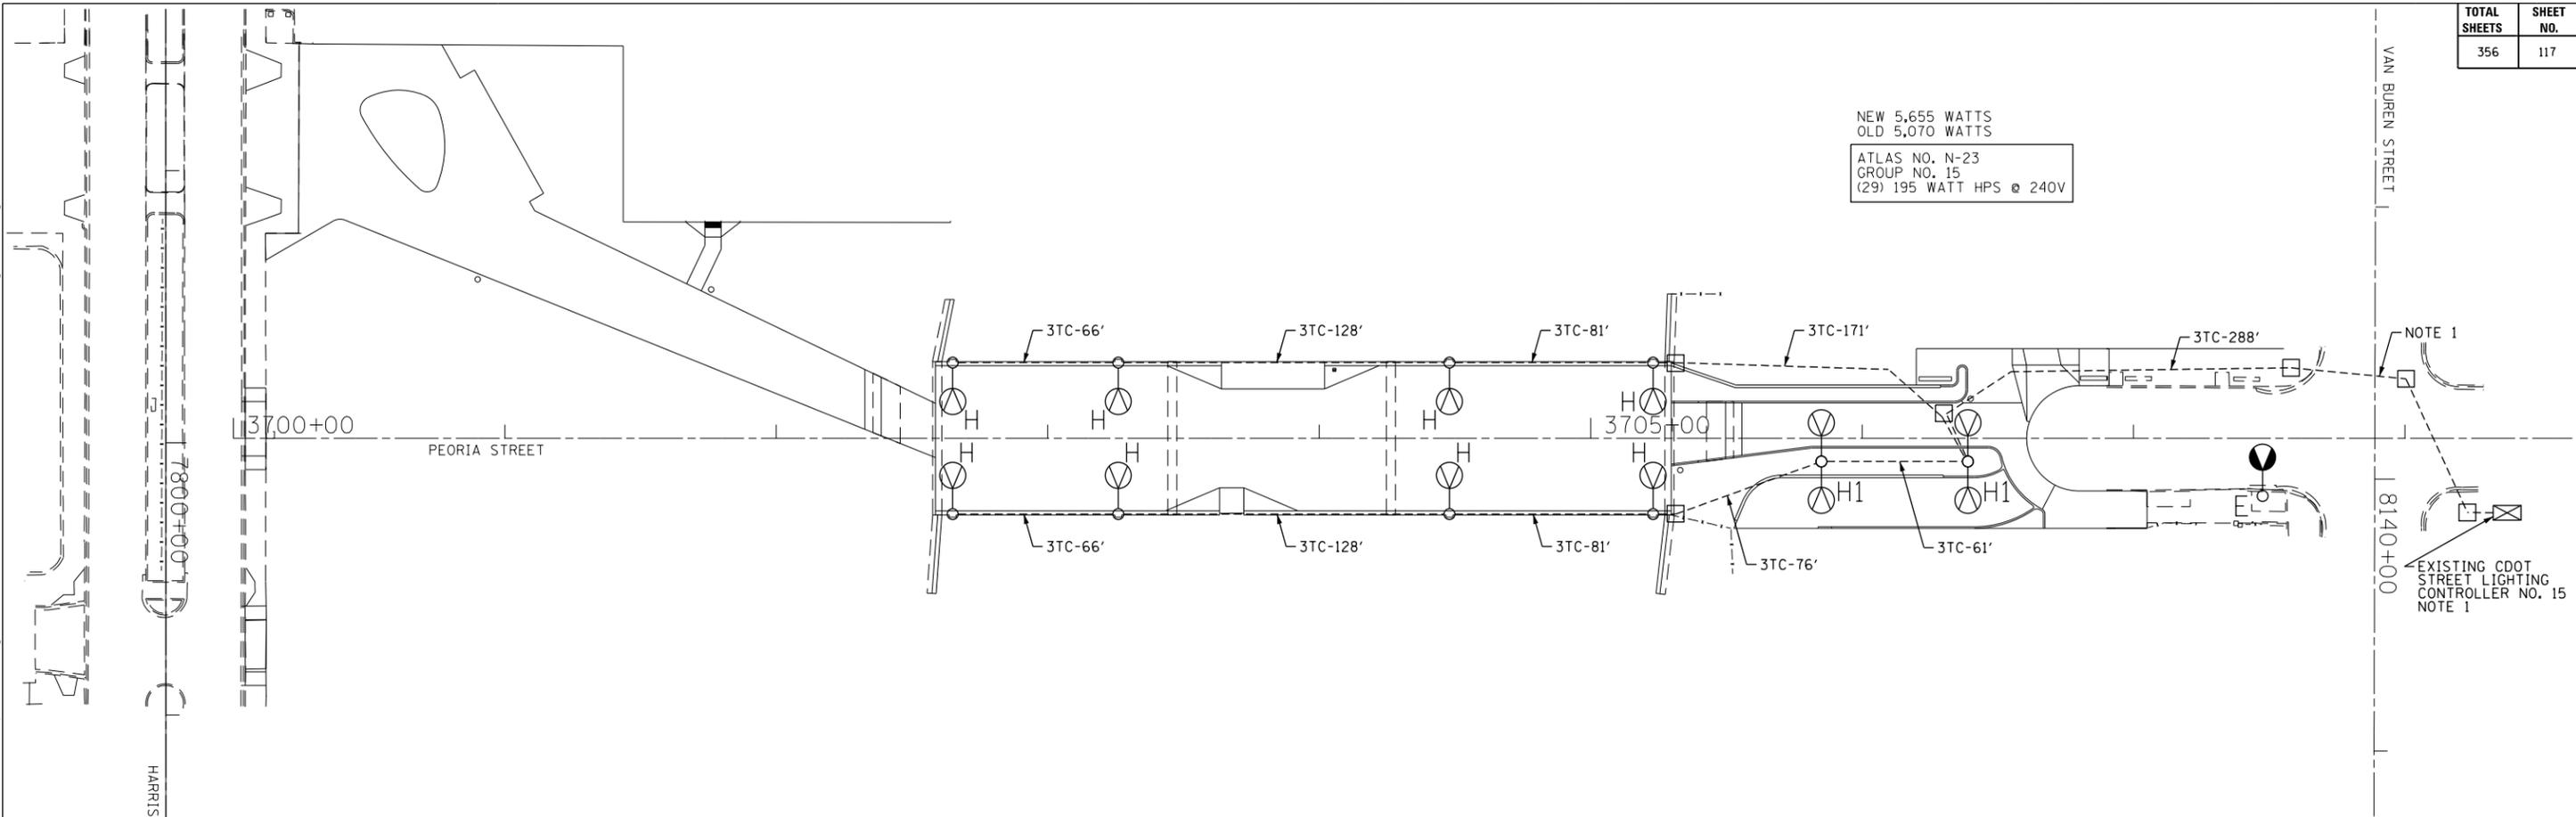

NEW 5,655 WATTS  
 OLD 5,070 WATTS  
 ATLAS NO. N-23  
 GROUP NO. 15  
 (29) 195 WATT HPS @ 240V

NOTE 1  
 EXISTING CDOT STREET LIGHTING CONTROLLER NO. 15  
 NOTE 1

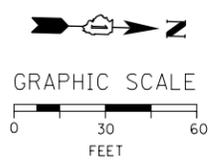

**NOTES:**

1. ROUTE NEW LIGHTING CIRCUIT THROUGH EXISTING CITY CONDUITS AND MANHOLES INTO THE EXISTING CDOT LIGHTING CONTROLLER AND MAKE THE NECESSARY CONNECTIONS TO THE EXISTING CIRCUIT BREAKERS. THIS WORK WILL NOT BE PAID FOR SEPARATELY AND SHALL BE INCLUDED IN THE COST OF THE "CABLE IN CONDUIT, TRIPLEX" PAY ITEM.

"H" PROVIDE 12.5' ALUMINUM POLE, 150W HPS LUMINAIRE AND 8 FOOT ALUMINUM DAVIT ARM PER DRAWING NOS. 940 AND 945.  
 "H1" PROVIDE 12.5' ALUMINUM POLE, TWO 150W HPS LUMINAIRES AND TWIN 8 FOOT DAVIT ARMS PER DRAWING NOS. 940 AND 945.

FOR CONDUIT AND FOUNDATION PLANS SEE DRAWING NO. E-06.  
 FOR LIGHTING REMOVAL PLANS SEE DRAWING NO. E-08.

DATE	REVISION
<b>CITY OF CHICAGO</b> DEPARTMENT OF TRANSPORTATION DIVISION OF ENGINEERING	
CONSULTANT: <b>AECOM</b> <small>303 EAST WACKER DRIVE, SUITE 1400          CHICAGO, IL 60601-5276          PHONE: (312) 313-7100 FAX: (312) 313-6800</small>	
WORK ORDER NO. _____	DATE _____
COST ALLOCATION ACCOUNT _____	
APPROPRIATION ACCOUNT _____	MATERIAL _____ LABOR _____
<b>PEORIA STREET</b> <b>LIGHTING CABLE AND EQUIPMENT</b> <b>INSTALLATION PLAN</b>	
<b>CITY OF CHICAGO</b> <small>DEPT. OF TRANSPORTATION          DIVISION OF ELECTRICAL OPERATIONS</small>	
DRAFTSMAN: CAM	ENGINEER: WDS
SUPERVISING ENGINEER: JPC	ELEC. DESIGN ENGR.:
ENGINEER OF ELECTRICITY:	
GEN'L SUPT. OF ELECTRICITY:	
DEPUTY COMMISSIONER:	
SIZE: 22"   34"	SCALE: 1" = 30'
DATE: 05/14/13	DATE:
C.D.O.T. PROJECT NO.:	DWG. NO.: 7 OF 19

E-07