


- NOTES:**
1. SEE SHEET NO. 424 FOR LEGEND AND GENERAL NOTES.
 2. SEE SHEET NO. 435 FOR COMBINATION LIGHTING CONTROLLER DIAGRAM.
 3. SEE TRAFFIC SIGNAL PLANS FOR COMBINATION POLE AND MAST ARM DETAILS.

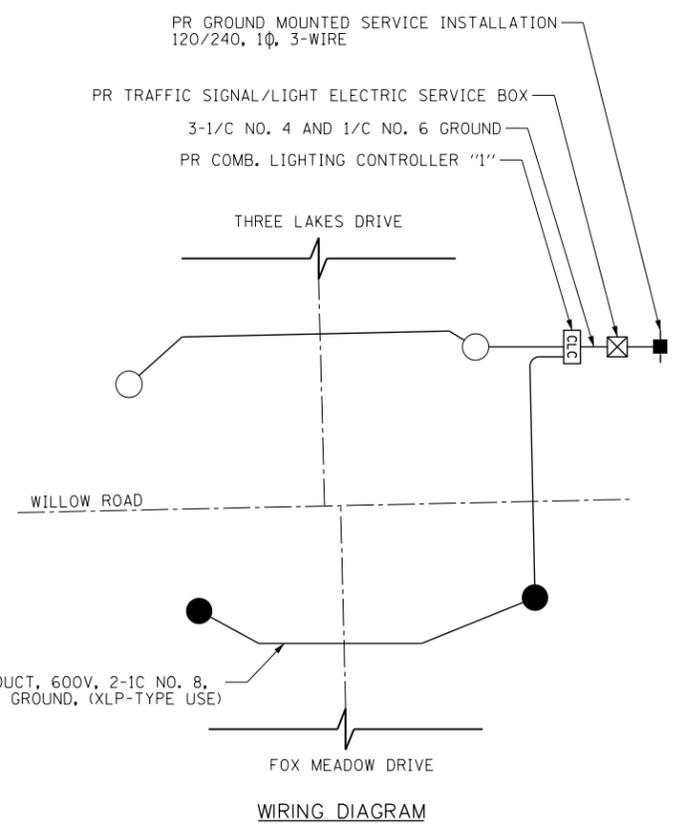

- LEGEND**
- LUMINAIRE, HPS, HORIZ. MOUNT, 250W, 240V, ON RED WIRE
 - LUMINAIRE, HPS, HORIZ. MOUNT, 250W, 240V, ON BLACK WIRE

FILE NAME =	USER NAME = BAW:tor.t	DESIGNED - SRF	REVISED -
G:\CH11\0158\Road\Road-CD\Lighting\0160135-SHT-LIGHT-02.dgn		DRAWN - AJP	REVISED -
PLOT SCALE = 40.000' / in.		CHECKED - SRF	REVISED -
PLOT DATE = 11/1/2012		DATE - 10/31/2012	REVISED -

**STATE OF ILLINOIS
DEPARTMENT OF TRANSPORTATION**

**LIGHTING PLAN
WILLOW ROAD AT THREE LAKES DRIVE / FOX MEADOW DRIVE**

F.A.P. RTE.	SECTION	COUNTY	TOTAL SHEETS	SHEET NO.
305	(1920.01,1518,2022&1922.4BR)	COOK	919	425
FED. ROAD DIST. NO. 1 ILLINOIS FED. AID PROJECT			CONTRACT NO. 60T35	

SCALE: 1" = 40' SHEET NO. 425 OF 919 SHEETS