
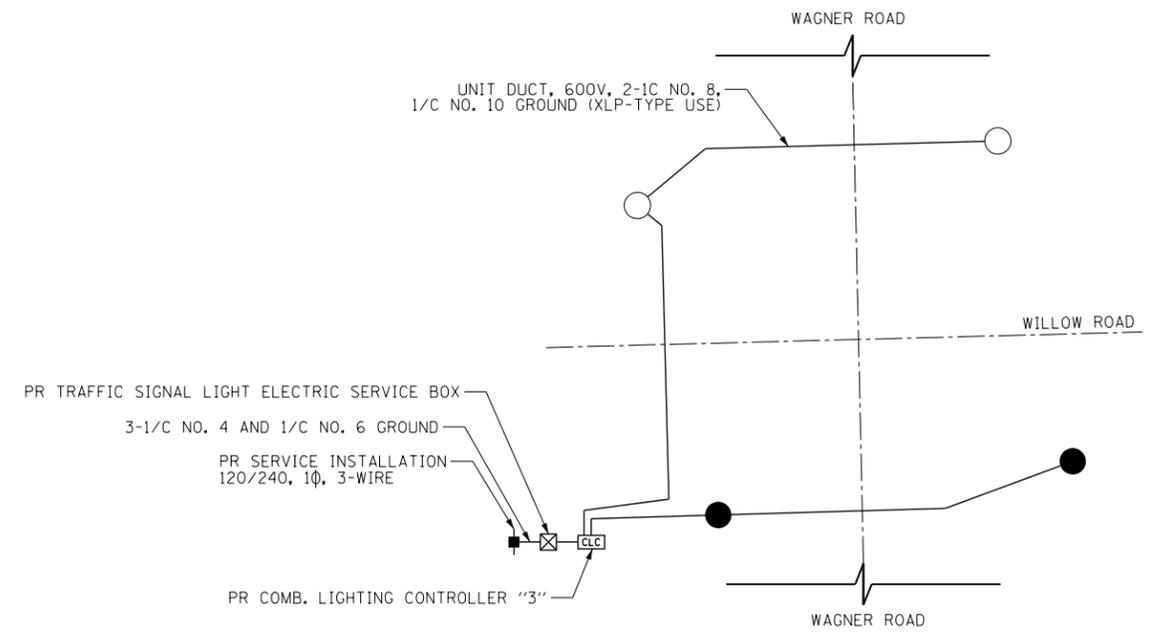


- NOTES:**
1. SEE SHEET NO. 424 FOR LEGEND AND GENERAL NOTES.
  2. SEE SHEET NO. 435 FOR COMBINATION LIGHTING CONTROLLER DIAGRAM.
  3. SEE TRAFFIC SIGNAL PLANS FOR COMBINATION POLE AND MAST ARM DETAILS.

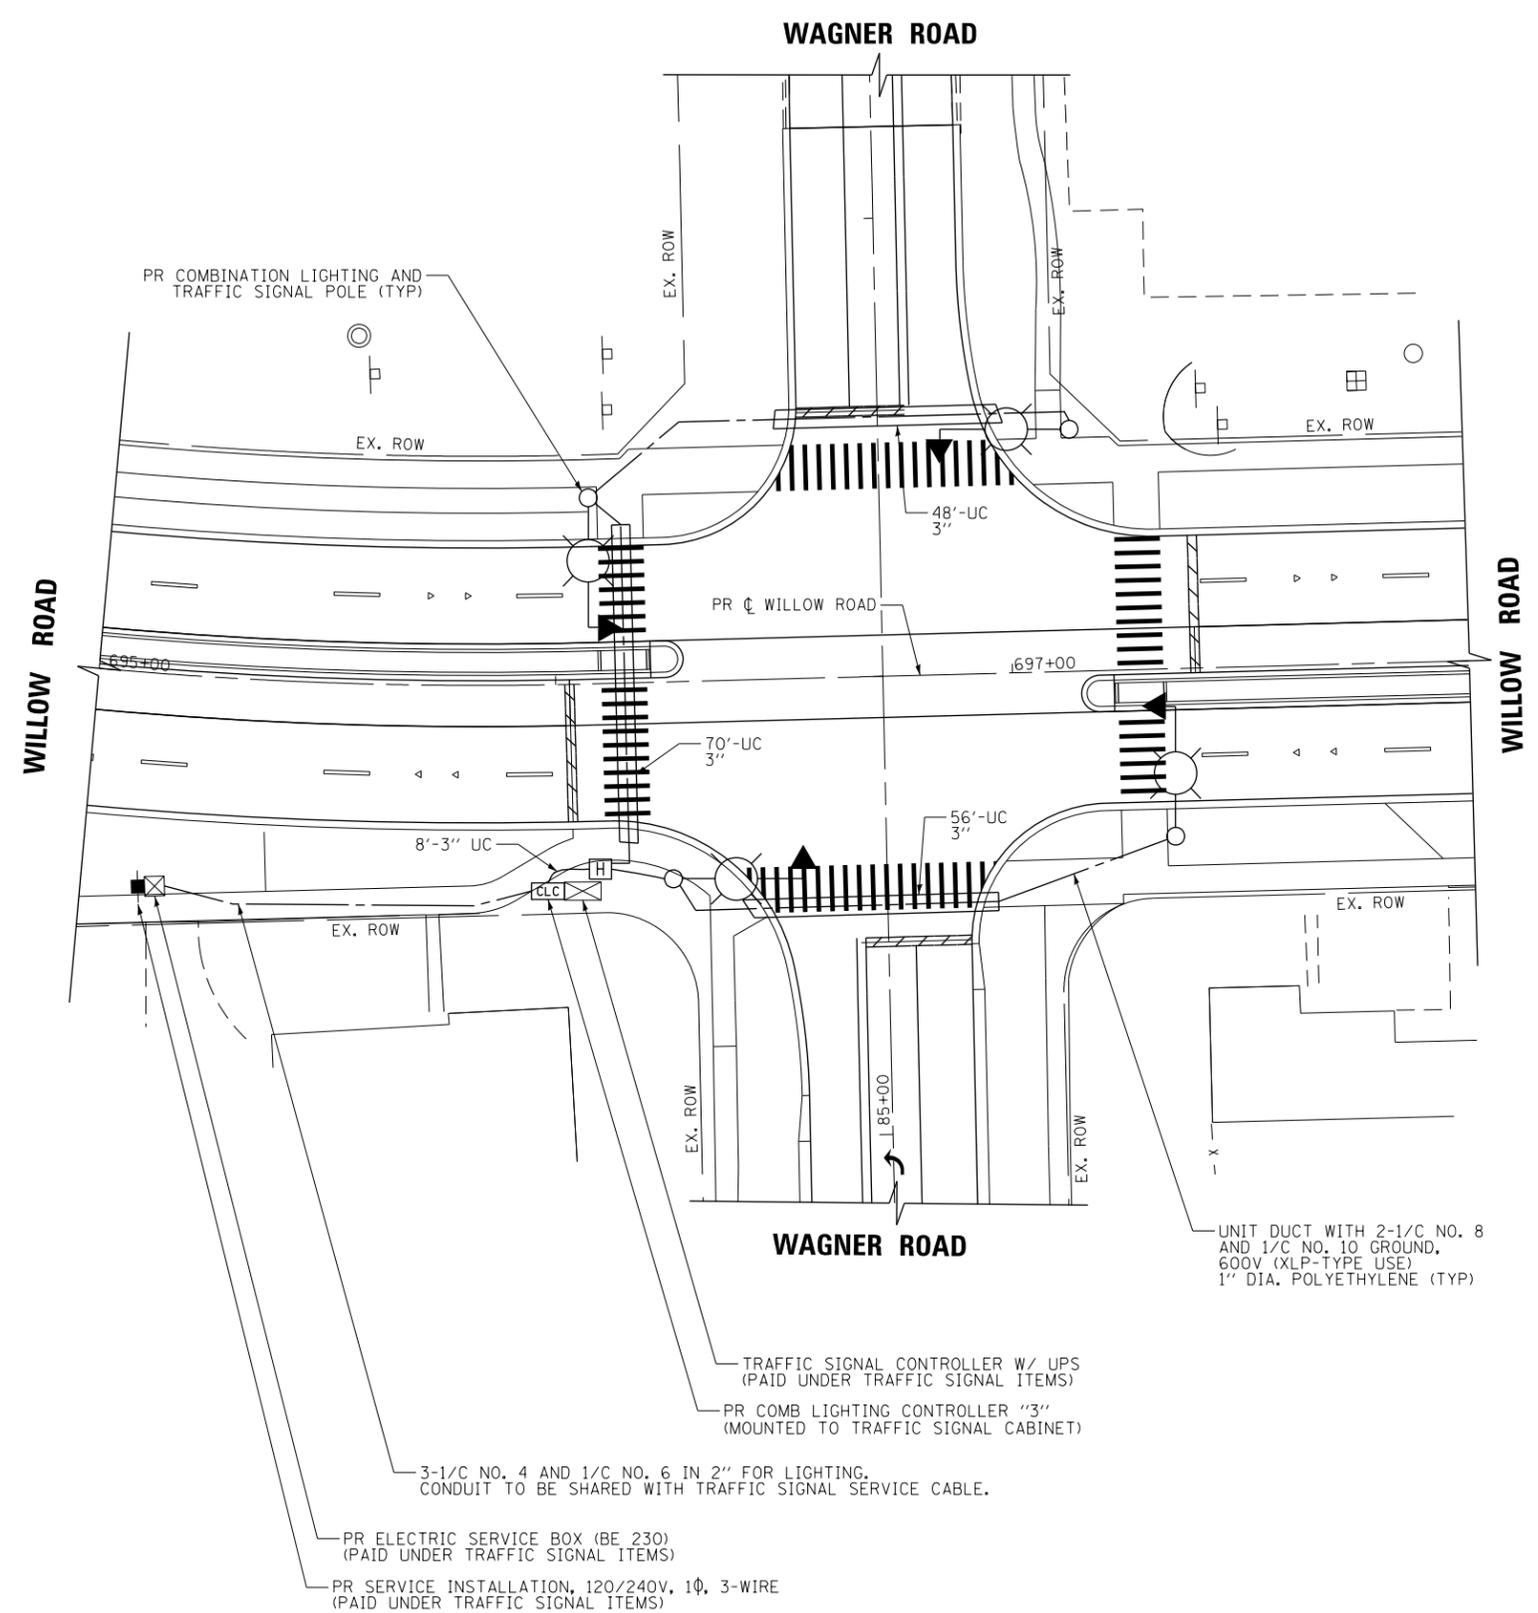

- LEGEND**
- LUMINAIRE, METAL HALIDE, HORIZ. MOUNT, 250W, 240V, ON RED WIRE
  - LUMINAIRE, METAL HALIDE, HORIZ. MOUNT, 250W, 240V, ON BLACK WIRE

**WIRING DIAGRAM**

FILE NAME = G:\CH11\0158\Road\Road-CD\Lighting\DI60135-SHT-LIGHT-04.dgn	USER NAME = BAW\ort	DESIGNED - SRF	REVISED -
PLOT SCALE = 40.000' / in.	CHECKED - SRF	DRAWN - AJP	REVISED -
PLOT DATE = 11/1/2012	DATE - 10/31/2012		REVISED -

**STATE OF ILLINOIS  
DEPARTMENT OF TRANSPORTATION**

**LIGHTING PLAN  
WILLOW ROAD AND WAGNER ROAD**

SCALE: 1" = 40' SHEET NO. 427 OF 919 SHEETS

F.A.P. RTE.	SECTION	COUNTY	TOTAL SHEETS	SHEET NO.
305	(1920.01,1518,2022&1922.4)R	COOK	919	427
FED. ROAD DIST. NO. 1 ILLINOIS FED. AID PROJECT			CONTRACT NO. 60T35	