
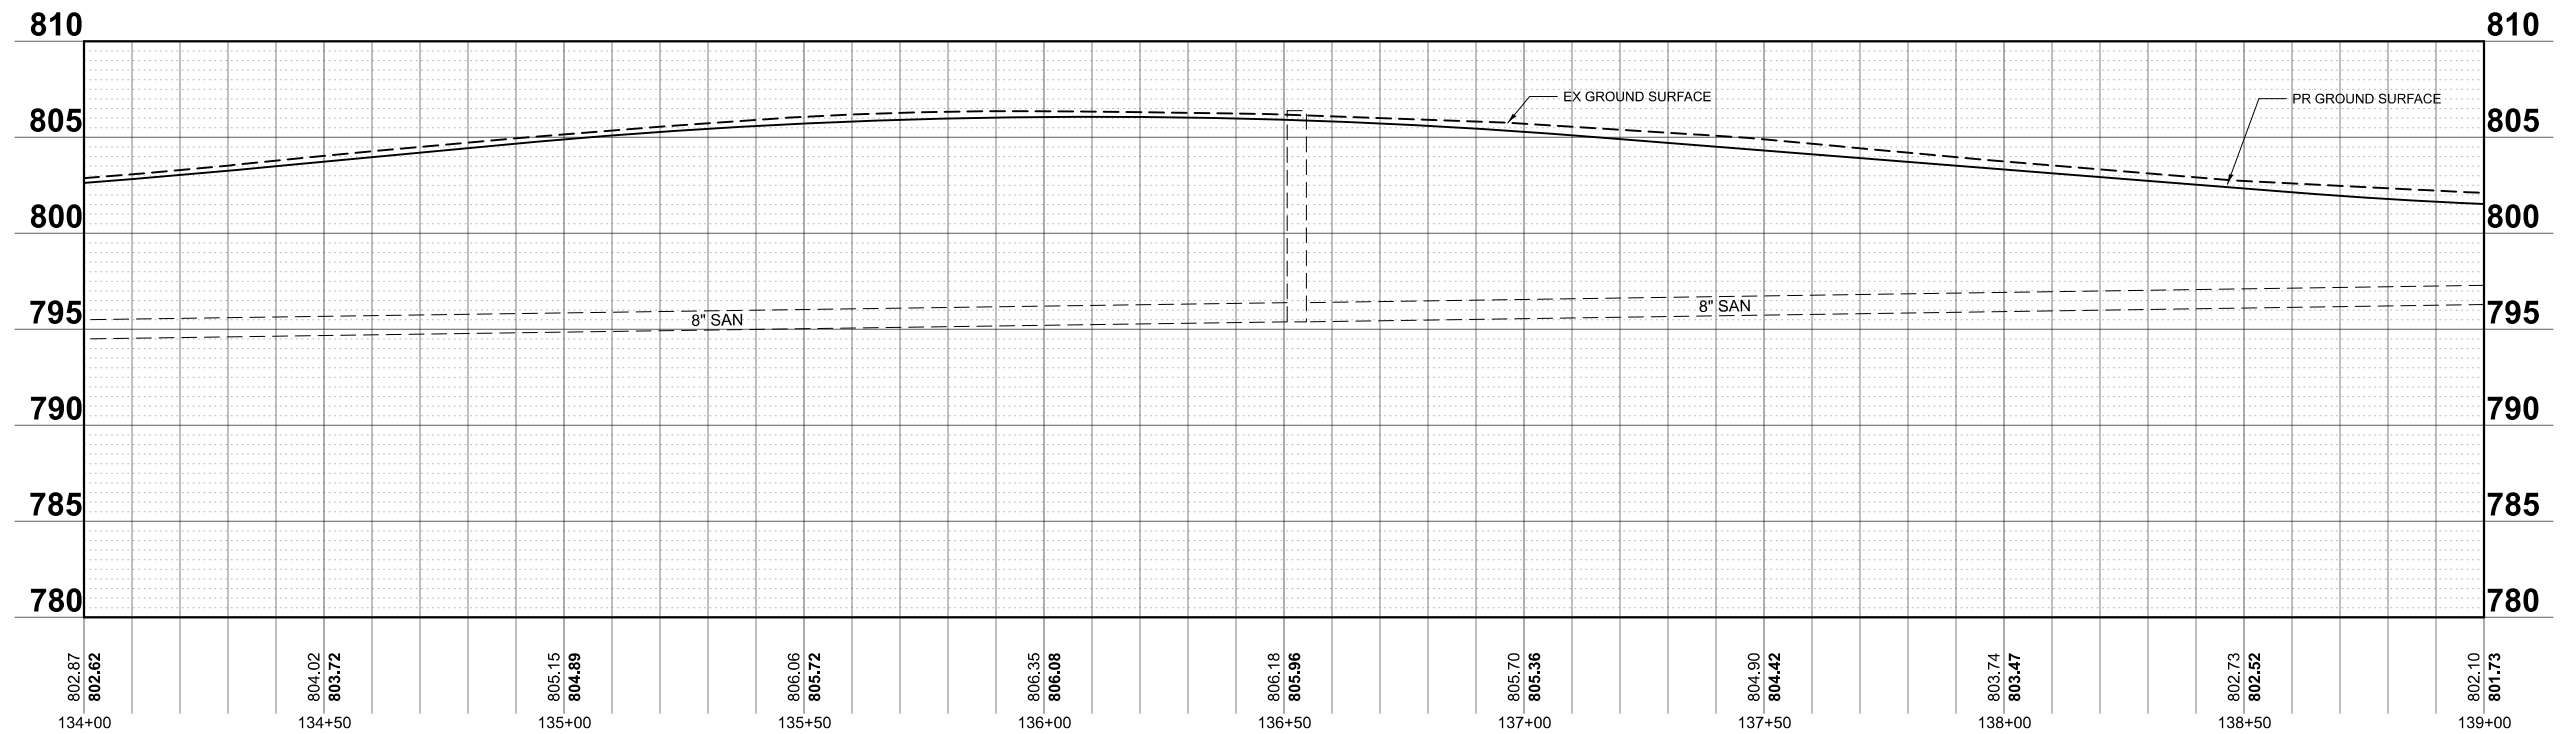


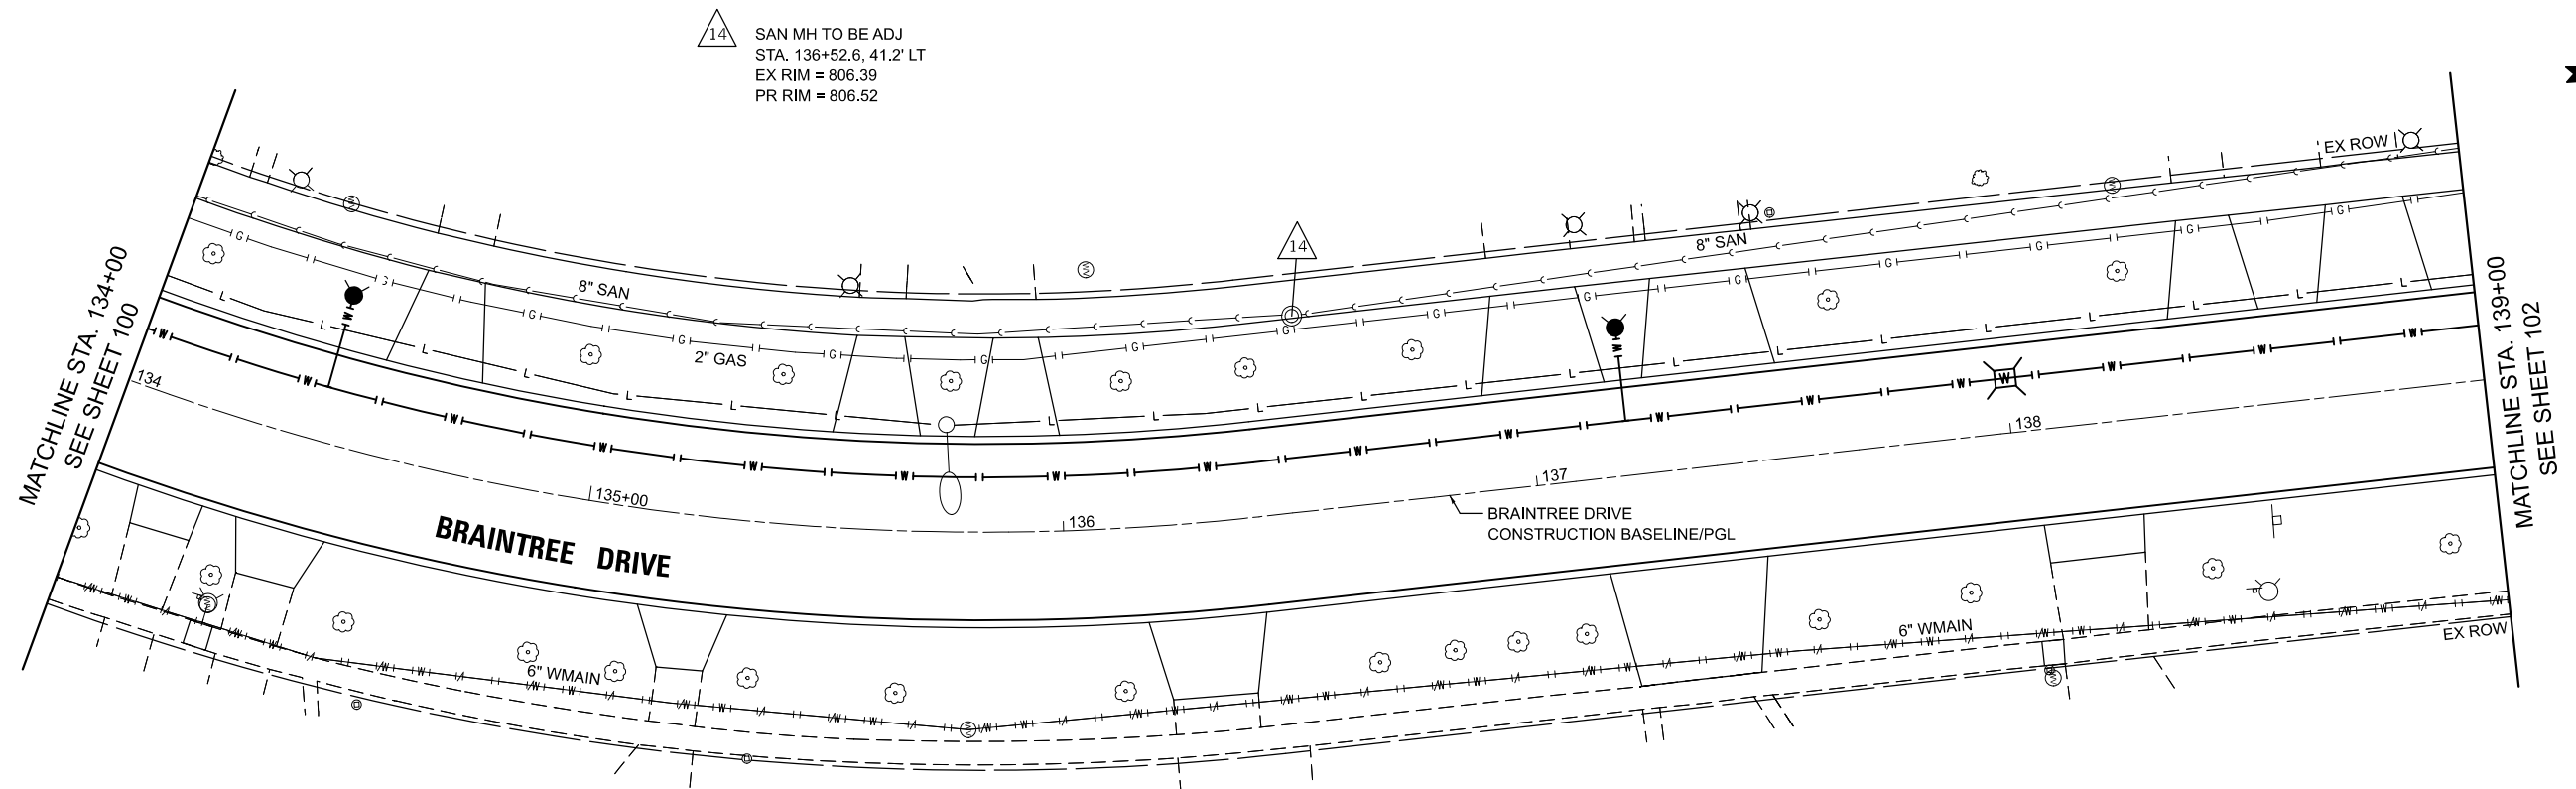

MODEL: Braintree - Sheet 8 [Sheet]
FILE NAME: c:\bns\shl\sch-pw\patro.kravets\0140565\3983.Dr\Us.dgn



USER NAME = pk	DESIGNED - EML	REVISED -
	DRAWN - EML	REVISED -
	CHECKED - TKL	REVISED -
PLOT DATE = 12/15/2025	DATE - 12/12/2025	REVISED -

STATE OF ILLINOIS
DEPARTMENT OF TRANSPORTATION

BRAINTREE DRIVE
DRAINAGE AND UTILITIES

SCALE: 1"=20' SHEET 8 OF 14 SHEETS STA. 134+00.00 TO STA. 139+00.00

MUN RTE.	SECTION	COUNTY	TOTAL SHEETS	SHEET NO.
4029	23-00146-00-PV	COOK	315	101
CONTRACT NO. 61M26				
ILLINOIS FED. AID PROJECT				

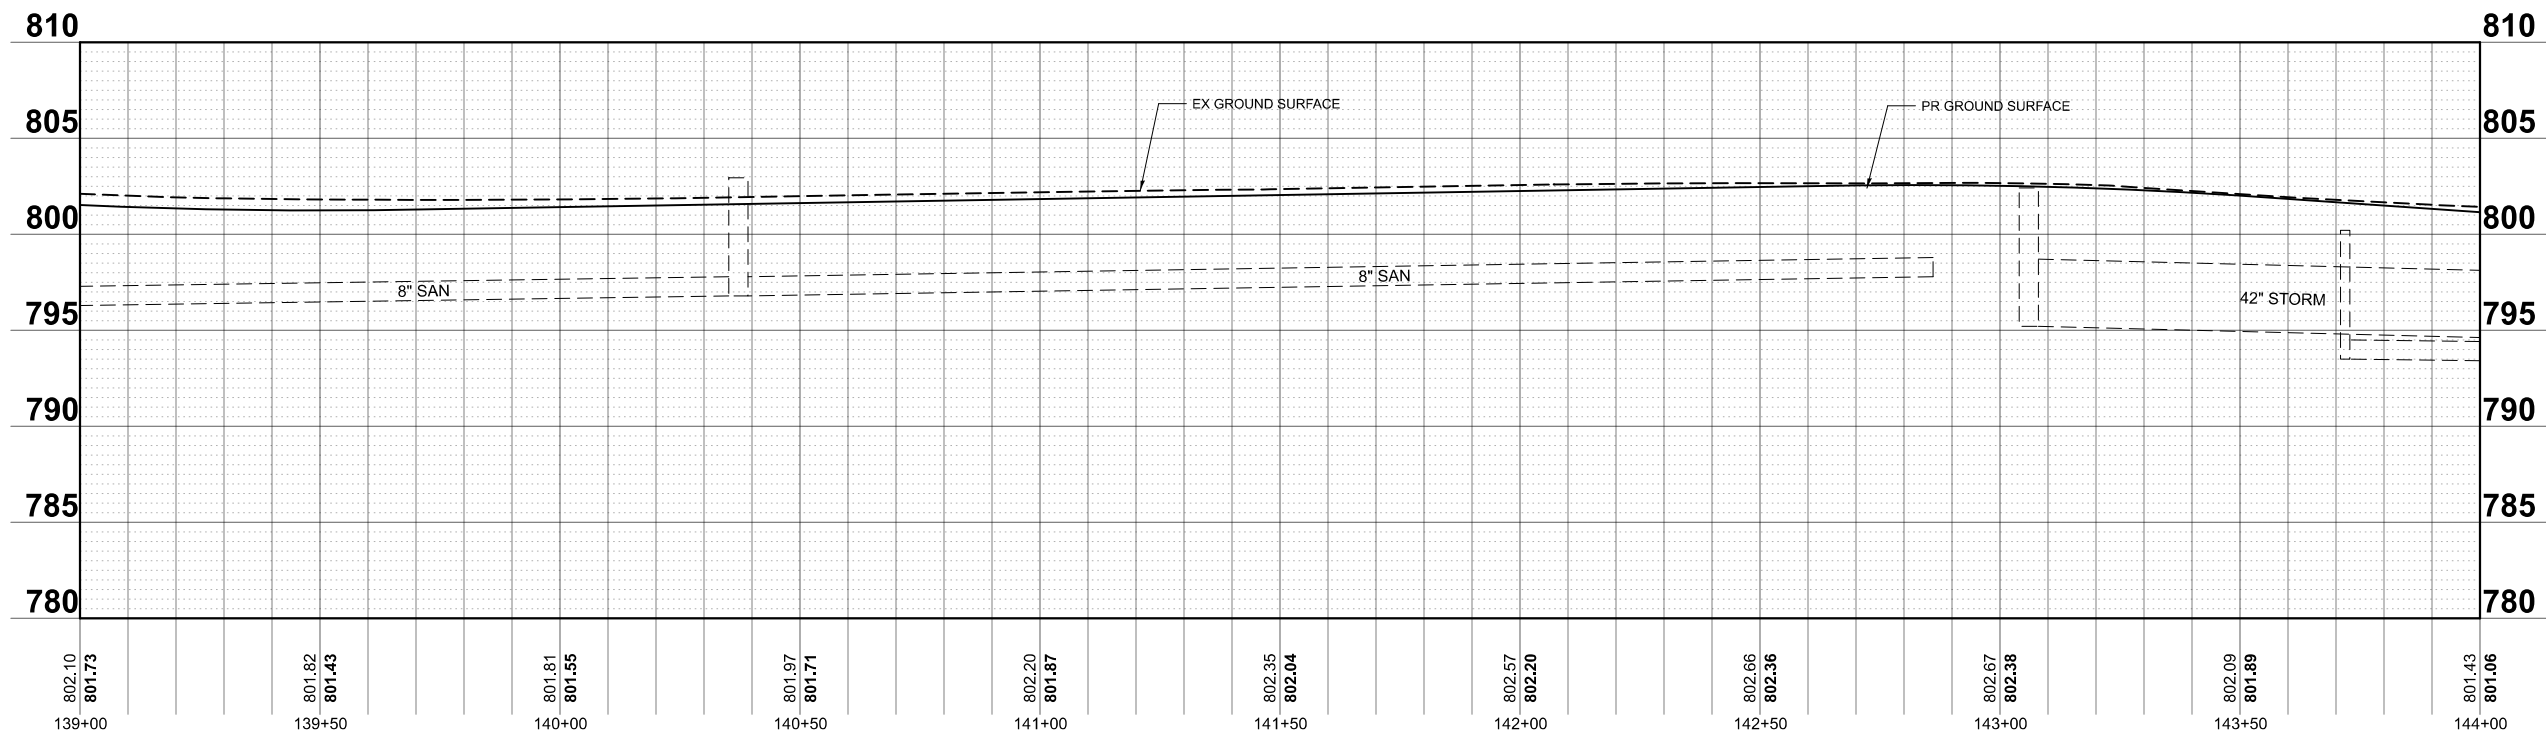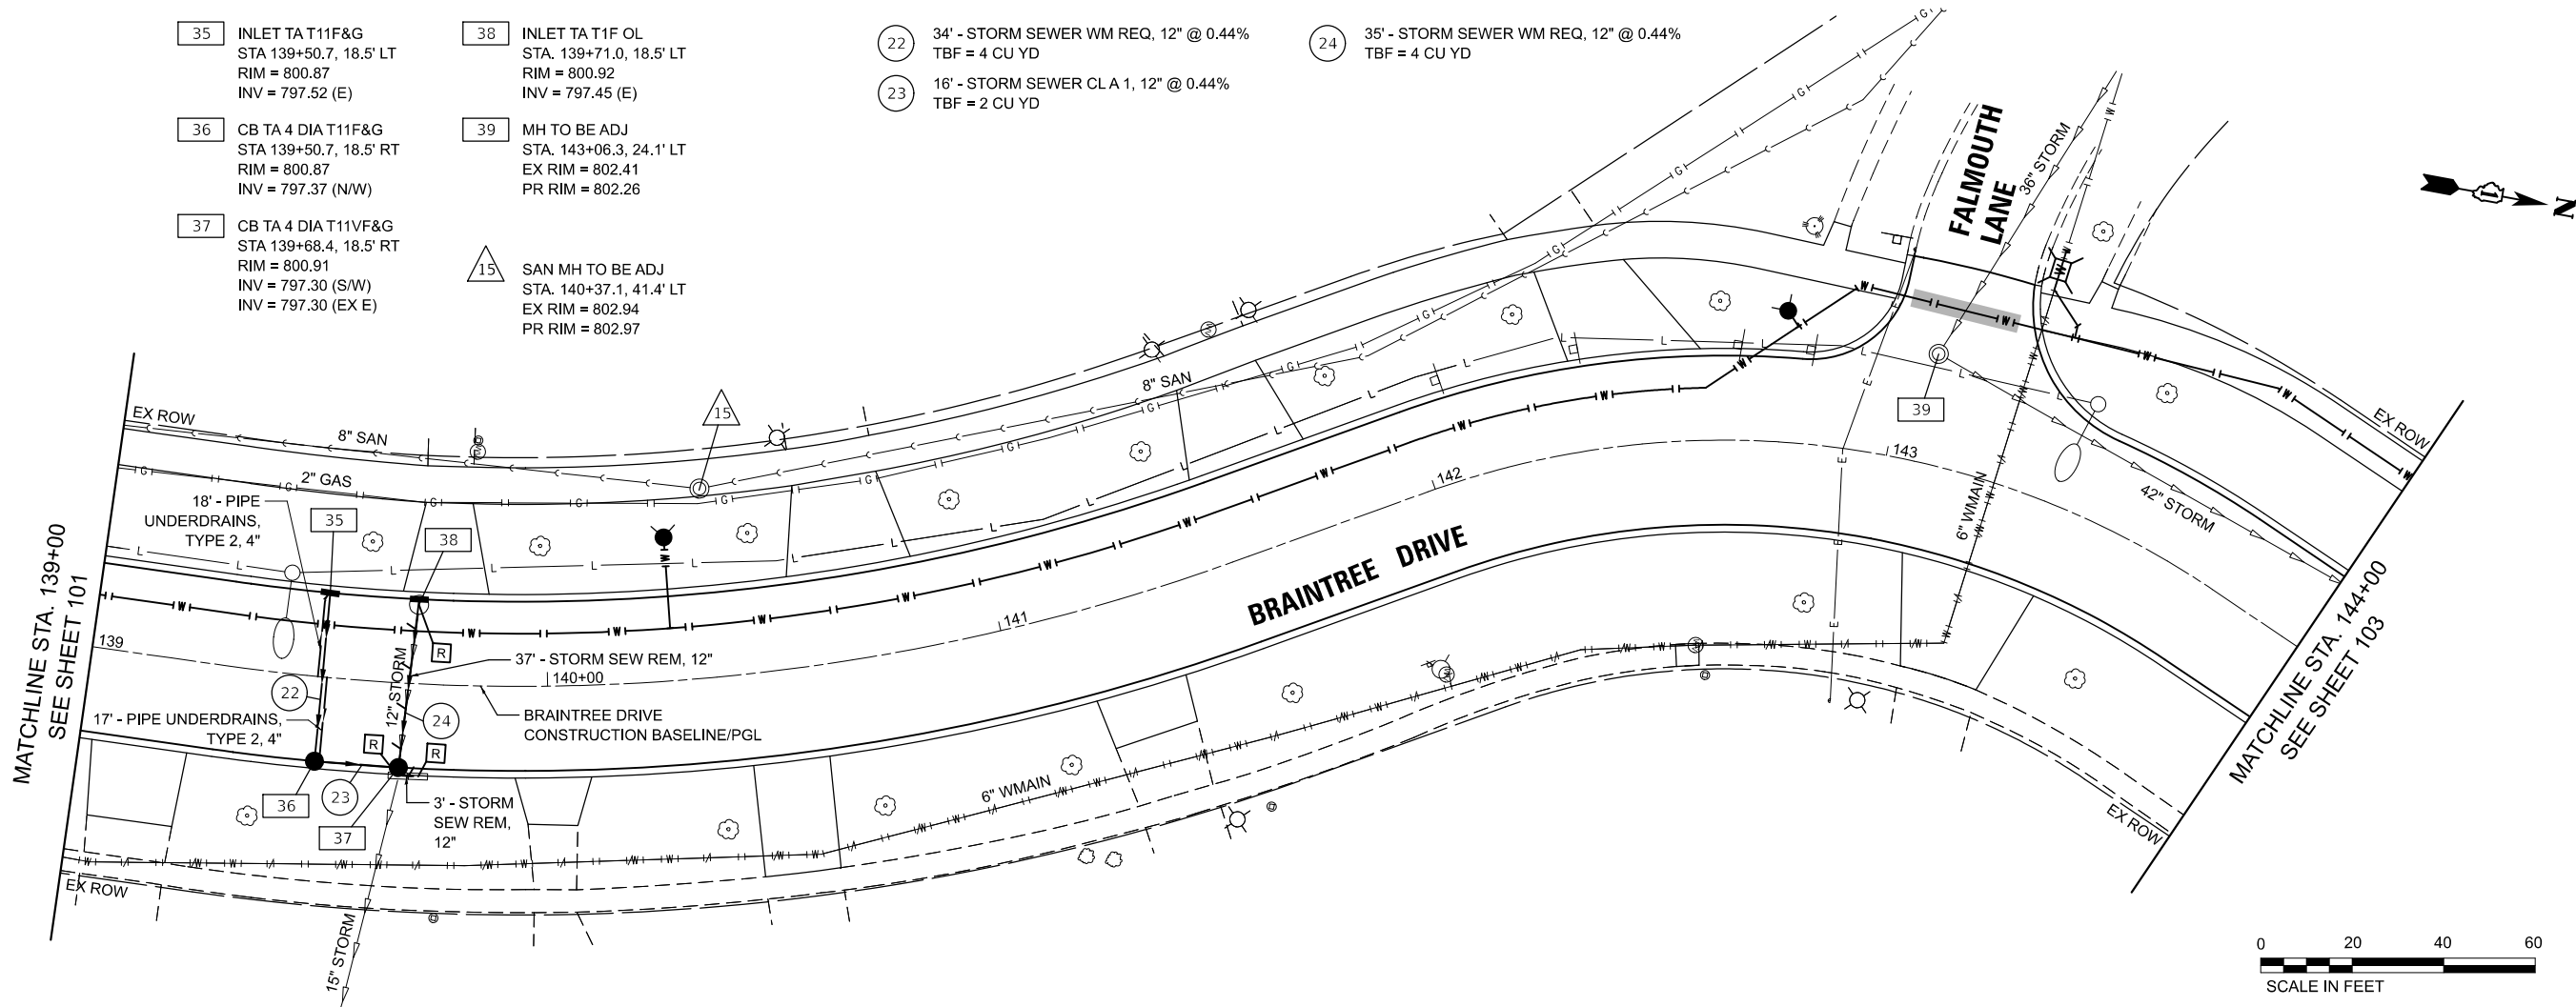

MODEL: Braintree - Sheet 9 [Sheet]
FILE NAME: c:\bns\dwg\sch-pw\braintree\braintree.dwg

USER NAME = EML	DESIGNED - EML	REVISED -
	DRAWN - EML	REVISED -
	CHECKED - TKL	REVISED -
PLOT DATE = 12/15/2025	DATE - 12/12/2025	REVISED -

STATE OF ILLINOIS
DEPARTMENT OF TRANSPORTATION

BRAINTREE DRIVE
DRAINAGE AND UTILITIES

SCALE: 1"=20' SHEET 9 OF 14 SHEETS STA. 139+00.00 TO STA. 144+00.00

MUN RTE.	SECTION	COUNTY	TOTAL SHEETS	SHEET NO.
4029	23-00146-00-PV	COOK	315	102
CONTRACT NO. 61M26				
ILLINOIS FED. AID PROJECT				

52 MH TO BE ADJ
STA. 150+66.5, 10.5' RT
EX RIM = 810.90
PR RIM = 810.59

53 INLET TA T11VF&G
STA. 151+40.1, 18.5' RT
RIM = 808.89
INV = 803.31 (NW)

54 CB TA 4 DIA T11VF&G
STA 151+62.5, 18.5' LT
RIM = 808.30
INV = 803.10 (NE/SE)

55 CB TA 4 DIA T11F&G
STA 151+89.6, 51.2' LT
RIM = 807.00
INV = 803.09 (EX 12" N)

56 MH TO BE ADJ
STA. 151+86.7, 7.3' LT
EX RIM = 808.31
PR RIM = 807.89
INV = 803.00 (SW)
INV = 794.51 (EX 48" N/EX 48" S)
INV = 800.81 (EX 24" W)

57 MH TO BE ADJ
STA. 152+09.0, 10.0' RT
EX RIM = 807.62
PR RIM = 807.25

58 MH TO BE RECON
STA. 152+11.9, 7.1' LT
EX RIM = 807.73
PR RIM = 807.24



59 CB TO BE ADJ
STA. 152+16.2, 55.4' LT
EX RIM = 806.75
PR RIM = 806.99

60 MH TO BE RECON
STA. 152+11.5, 20.0' LT
EX RIM = 807.48
PR RIM = 807.02

18 SAN MH TO BE ADJ
STA. 149+49.0, 31.2 RT
EX RIM = 811.42
PR RIM = 811.30

27 41' - STORM SEW CL A 2, 12" @ 0.50%
TBF = 13 CU YD

28 20' - STORM SEWER WM REQ, 12" @ 0.50%
TBF = 6 CU YD

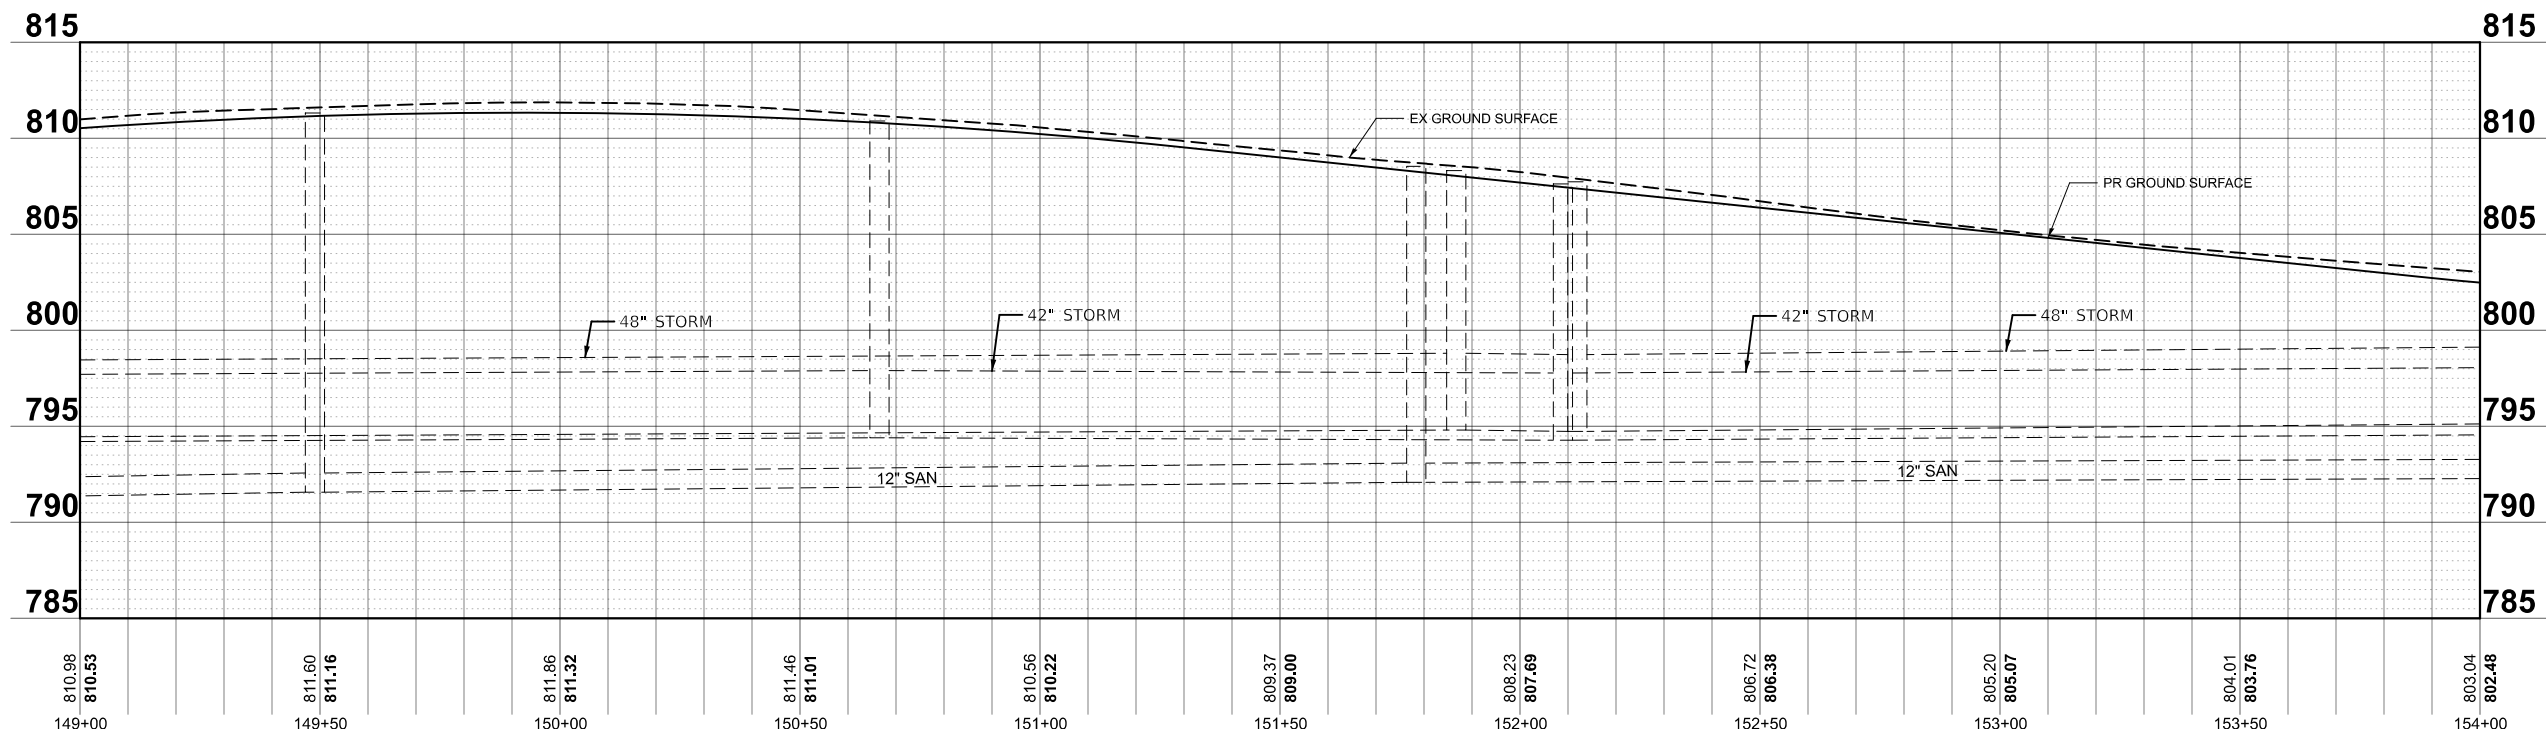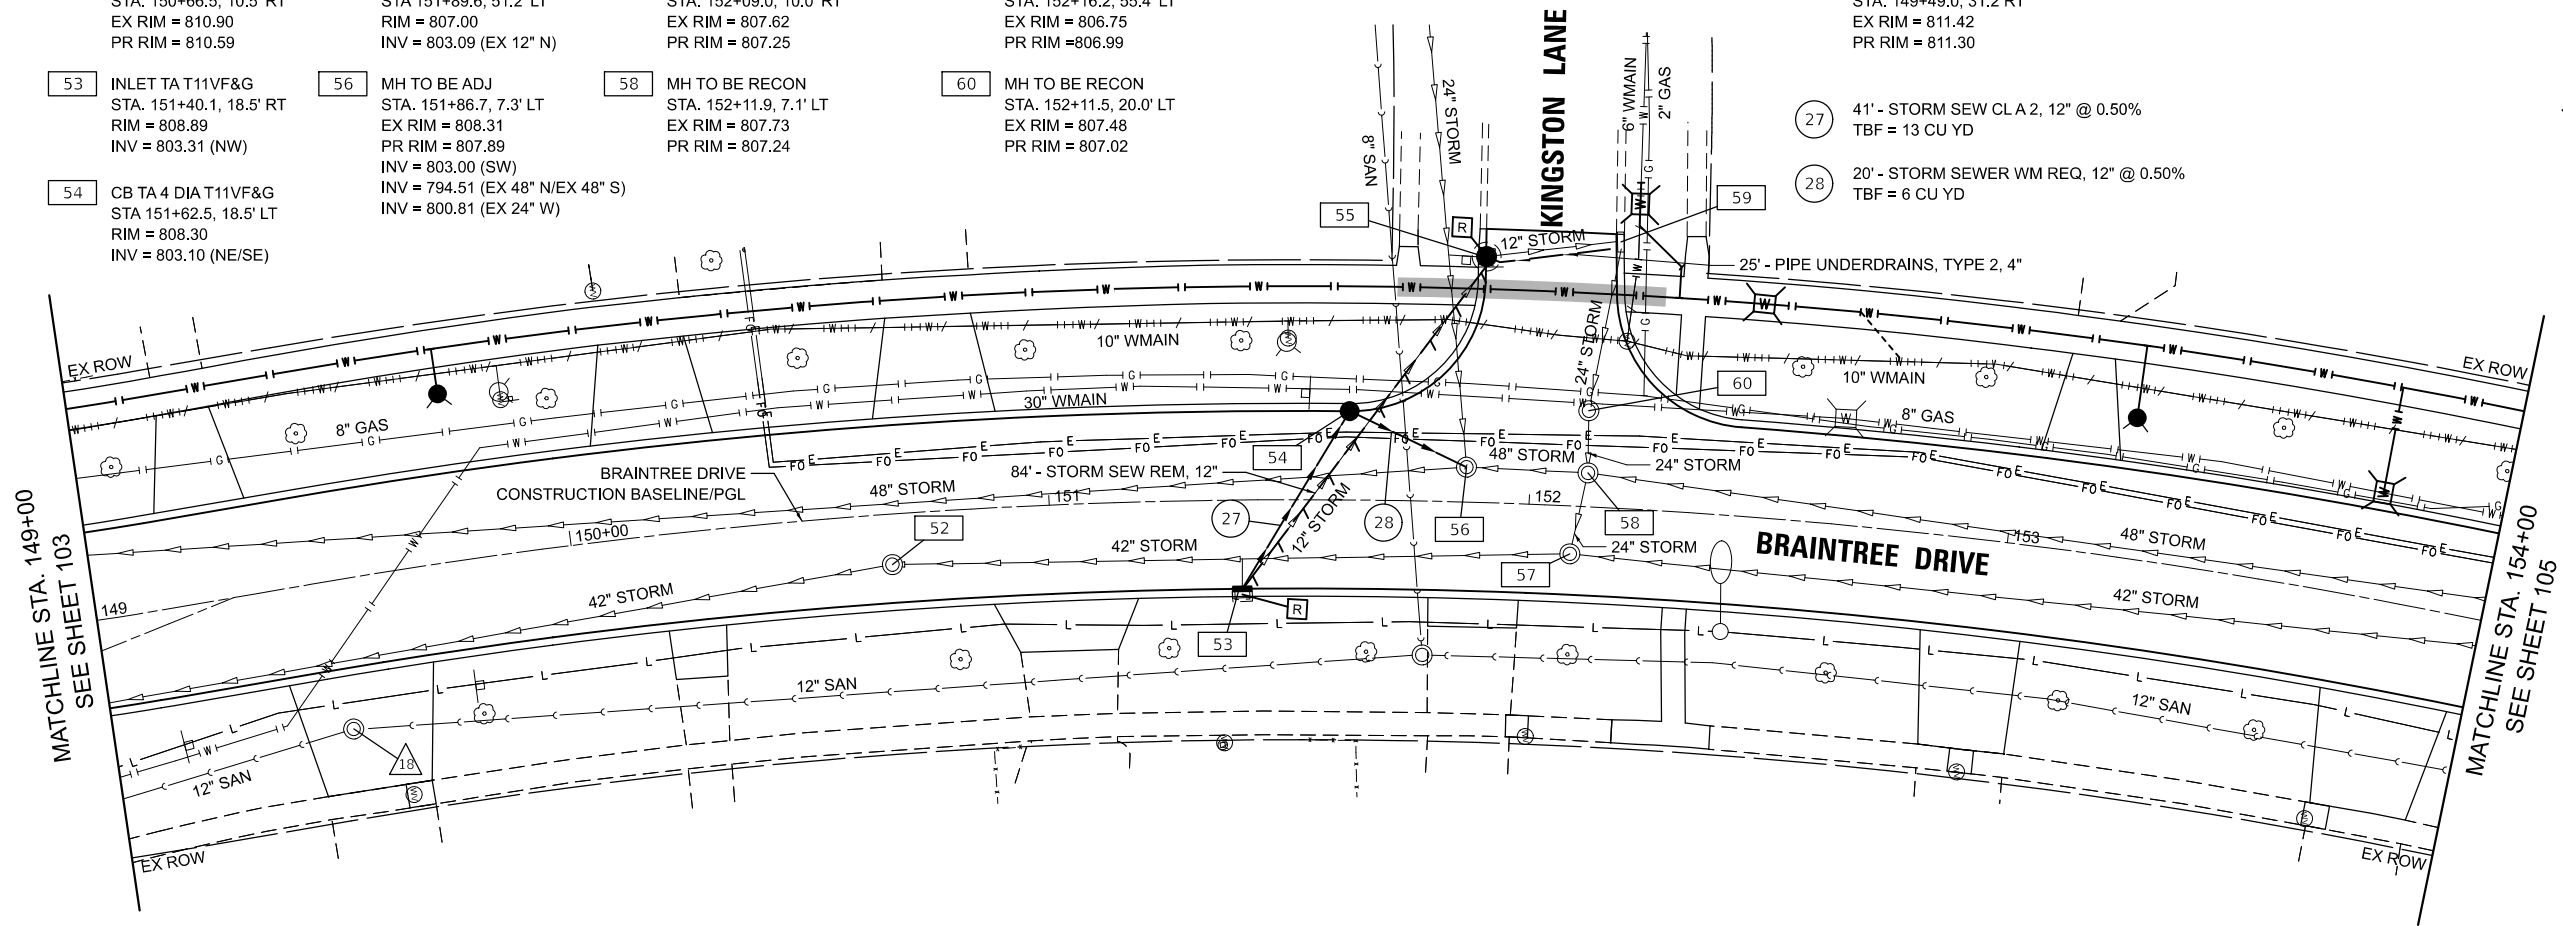

MODEL: Braintree - Sheet 11 [Sheet]
FILE NAME: c:\bns\dwg\tech-pw\pairo.kravets\0140565\3983.DrUs.dgn

USER NAME = pk	DESIGNED - EML	REVISED -
	DRAWN - EML	REVISED -
	CHECKED - TKL	REVISED -
PLOT DATE = 12/15/2025	DATE - 12/12/2025	REVISED -

STATE OF ILLINOIS
DEPARTMENT OF TRANSPORTATION

BRAINTREE DRIVE DRAINAGE AND UTILITIES			
SCALE: 1"=20'	SHEET 11	OF 14 SHEETS	STA. 149+00.00 TO STA. 154+00.00

MUN RTE. 4029	SECTION 23-00146-00-PV	COUNTY COOK	TOTAL SHEETS 315	SHEET NO. 104
CONTRACT NO. 61M26				
ILLINOIS FED. AID PROJECT				

61 CB TA BE RECON
STA. 154+20.8, 19.9' LT
EX RIM = 802.01
PR RIM = 801.68

62 MH TO BE ADJ
STA. 154+19.6, 5.9' LT
EX RIM = 802.46
PR RIM = 801.95
INV = 797.16 (N)
INV = UNK (EX 48" NE)
INV = 795.36 (EX 12" E)
INV = 795.16 (EX 48" S)
INV = 795.16 (EX 18" W)

63 MH TO BE RECON
STA. 154+18.0, 3.4' RT
EX RIM = 802.72
PR RIM = 802.03

64 MH TO BE ADJ
STA. 154+83.2, 46.2' LT
EX RIM = 801.14
PR RIM = 801.33

65 MAN TA 5 DIA T1F CL
STA 154+83.9, 7.5' LT
RIM = 801.10
INV = 797.43 (N/S)

66 CB TA 4 DIA T11VF&G
STA. 154+87.1, 18.6' RT
RIM = 800.86
INV = 795.02 (N/W)

67 MAN TA 6 DIA T1F CL
STA 154+87.7, 13.2' RT
RIM = 800.96
INV = 794.62 (EX 42" N/EX 42" S)
INV = 795.00 (E)

68 CB TA 4 DIA T11F&G
STA 155+17.3, 17.6' LT
RIM = 800.79
INV = 797.56 (S)

69 INLETS TA T11F&G
STA 155+17.8, 18.0' RT
RIM = 800.78
INV = 795.16 (S)

70 CB TA 4 DIA T11VF&G
STA. 155+72.4, 21.2' LT
RIM = 801.12
INV = 795.97 (E)

71 MH TO BE ADJ
W NEW T1F OL
(ADA COMPLIANT)
STA. 155+83.7, 48.3' LT
EX RIM = 800.35
PR RIM = 800.35

72 MH TO BE ADJ
STA. 402+62.6, 30.8' RT
EX RIM = 800.37
PR RIM = 801.34

73 CB TA 4 DIA T1F OL
STA. 402+07.1, 38.7' RT
RIM = 800.60
INV = 796.83 (NE)

74 MAN TA 7 DIA T11VF&G
STA 155+81.7, 20.7' RT
RIM = 801.04
INV = 794.74 (N/EX 42" S)
INV = 795.40 (W)

75 CB TA 4 DIA T11VF&G
STA 403+65.4, 22.0' RT
RIM = 800.76
INV = 795.08 (NE)

76 CB TA 4 DIA T11VF&G
STA 402+23.8, 16.9' RT
RIM = 801.23
INV = 796.72 (N/E/SW)

77 CB TA 4 DIA T11F&G
STA 402+66.7, 21.5' RT
RIM = 801.02
INV = 796.60 (W/NE/EX 15" S)

78 INLETS TA T11VF&G
STA 402+24.1, 17.8' LT
RIM = 801.19
INV = 796.86 (S)

79 CB TA 4 DIA T11F&G
STA 402+57.7, 26.5' LT
RIM = 800.94
INV = 796.79 (S)

80 CB TA 4 DIA T11VF&G
STA 403+65.4, 21.2' LT
RIM = 800.99
INV = 794.91 (NW/SW/E)

81 MAN TA 6 DIA T11VF&G
STA 156+64.5, 39.5' RT
RIM = 801.40
INV = 794.84 (SW/SE)
INV = 795.44 (N)

82 CB TA 5 DIA T11VF&G
STA 156+97.2, 20.9' RT
RIM = 801.29
INV = 795.53 (NE/SE/NW)

83 MAN TA 7 DIA T8G
STA 156+91.0, 28.9' RT
RIM = 801.61
INV = 795.48 (S/NW)
INV = 797.19 (EX 21" NE)

84 CB TA 4 DIA T11VF&G
STA 404+29.7, 17.5' RT
RIM = 800.38
INV = 796.17 (N)
INV = 797.02 (EX 12" S)

85 CB TA 4 DIA T11F&G
STA 404+45.8, 17.9' RT
RIM = 800.36
INV = 796.42 (N)
INV = 796.47 (EX 12" S)

86 CB TA 4 DIA T11VF&G
STA 404+41.7, 16.9' LT
RIM = 800.64
INV = 796.02 (S)
INV = 795.97 (N)


87 CB TA 5 DIA T11F&G
STA 404+26.2, 17.0' LT
RIM = 800.57
INV = 796.02 (S)
INV = 795.02 (W)
INV = 795.12 (NE)

88 CB TA 4 DIA T11VF&G
STA 157+04.6, 19.2' LT
RIM = 801.16
INV = 795.70 (E)


89 INLETS TA T11F&G
STA 157+35.0, 17.0' LT
RIM = 801.10
INV = 795.83 (E)

90 CB TA 4 DIA T11F&G
STA 157+35.0, 17.0' RT
RIM = 801.10
INV = 795.69 (W/S)



MATCHLINE STA. 154+00
SEE SHEET 104

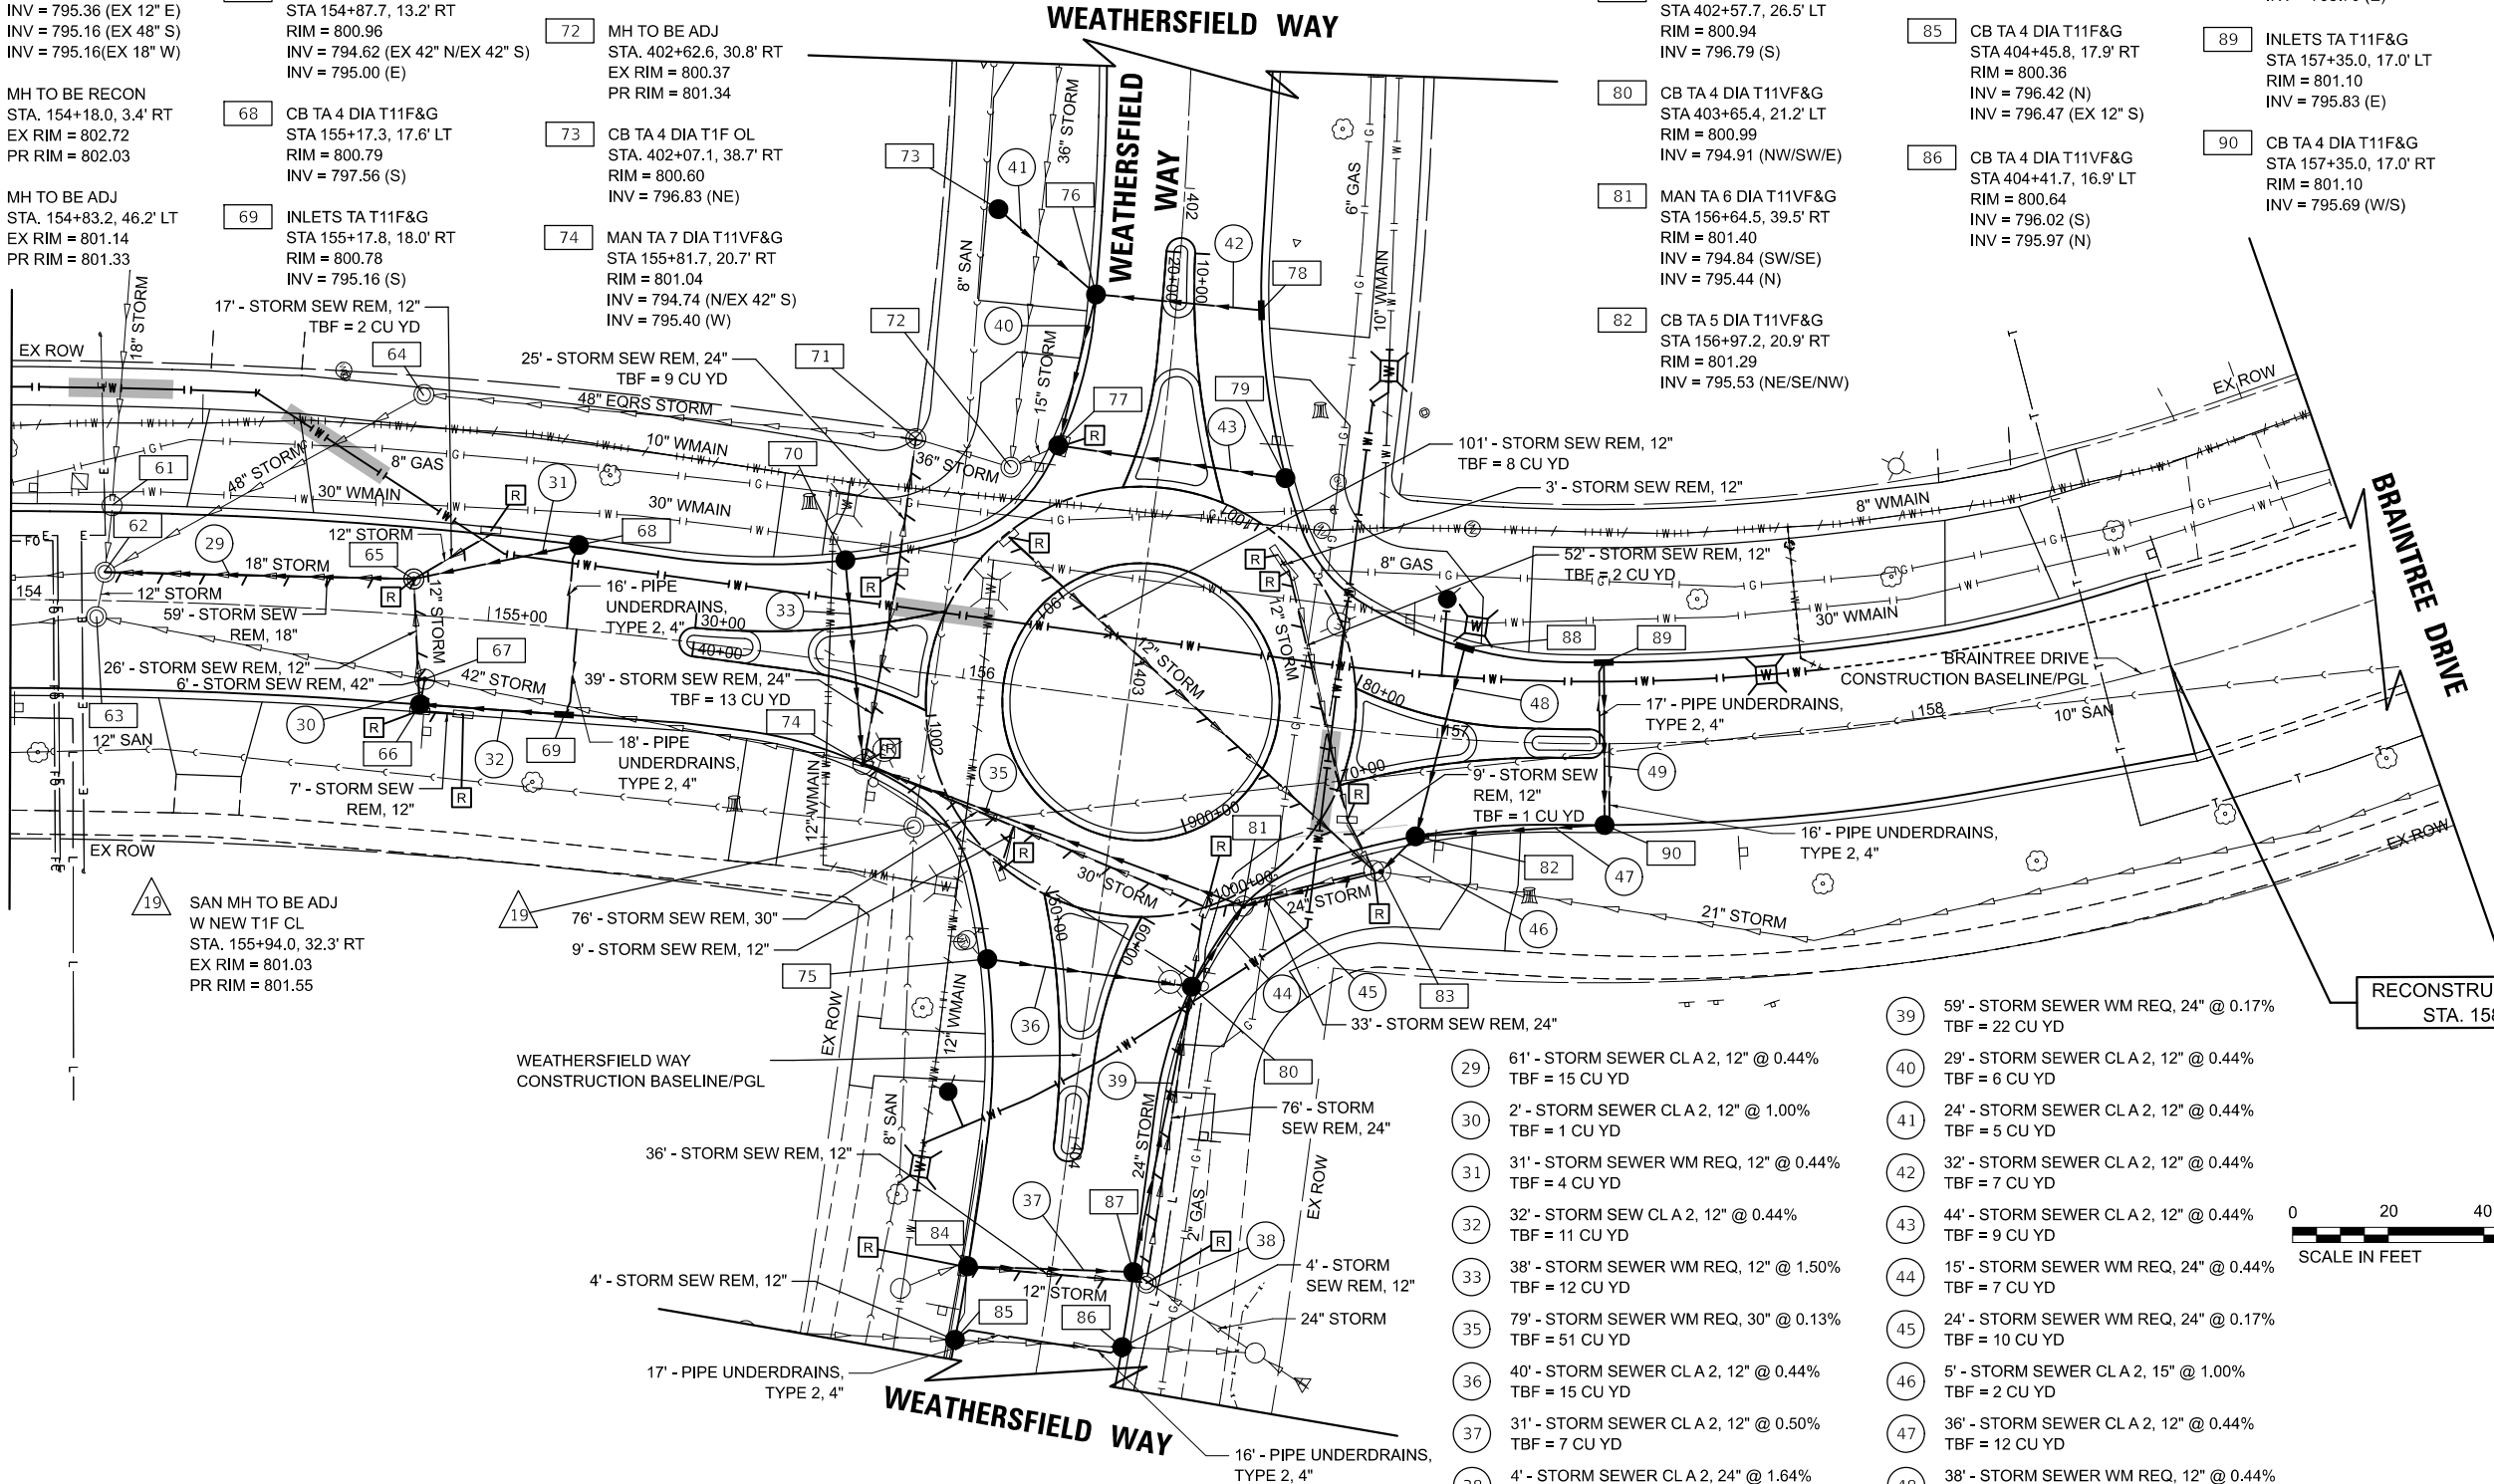

MODEL: Braintree - Sheet 12-2
FILE NAME: c:\bms\dwg\tech-pw\patro.kravets\0140565\3983.DrUs.dgn

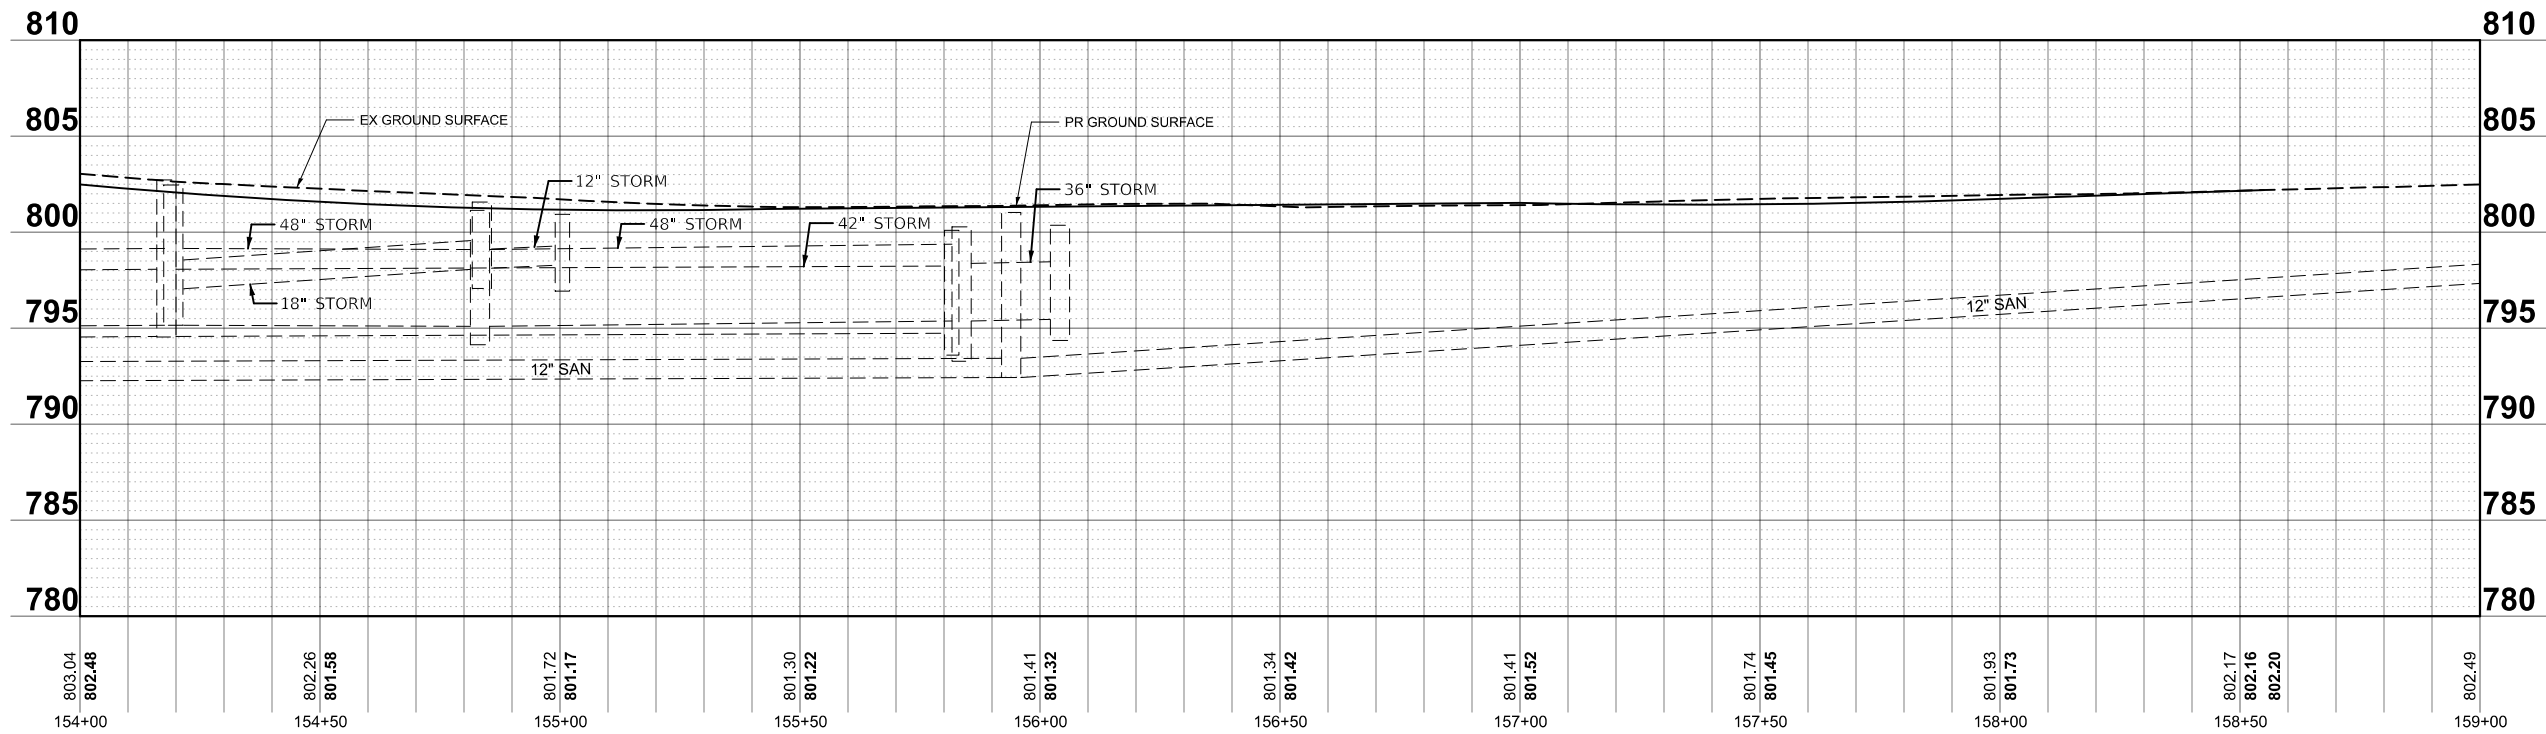

	USER NAME = pk	DESIGNED - EML	REVISED -	STATE OF ILLINOIS DEPARTMENT OF TRANSPORTATION	BRAINTREE DRIVE DRAINAGE AND UTILITIES			MUN. RTE. 4029	SECTION 23-00146-00-PV	COUNTY COOK	TOTAL SHEETS 315	SHEET NO. 106
		DRAWN - EML	REVISED -									
		CHECKED - TKL	REVISED -					CONTRACT NO. 61M26				
	PLOT DATE = 12/15/2025	DATE - 12/12/2025	REVISED -		SCALE: 1"=20'	SHEET 13	OF 14 SHEETS	STA. 154+00.00	TO STA. 159+00.00	ILLINOIS FED. AID PROJECT		

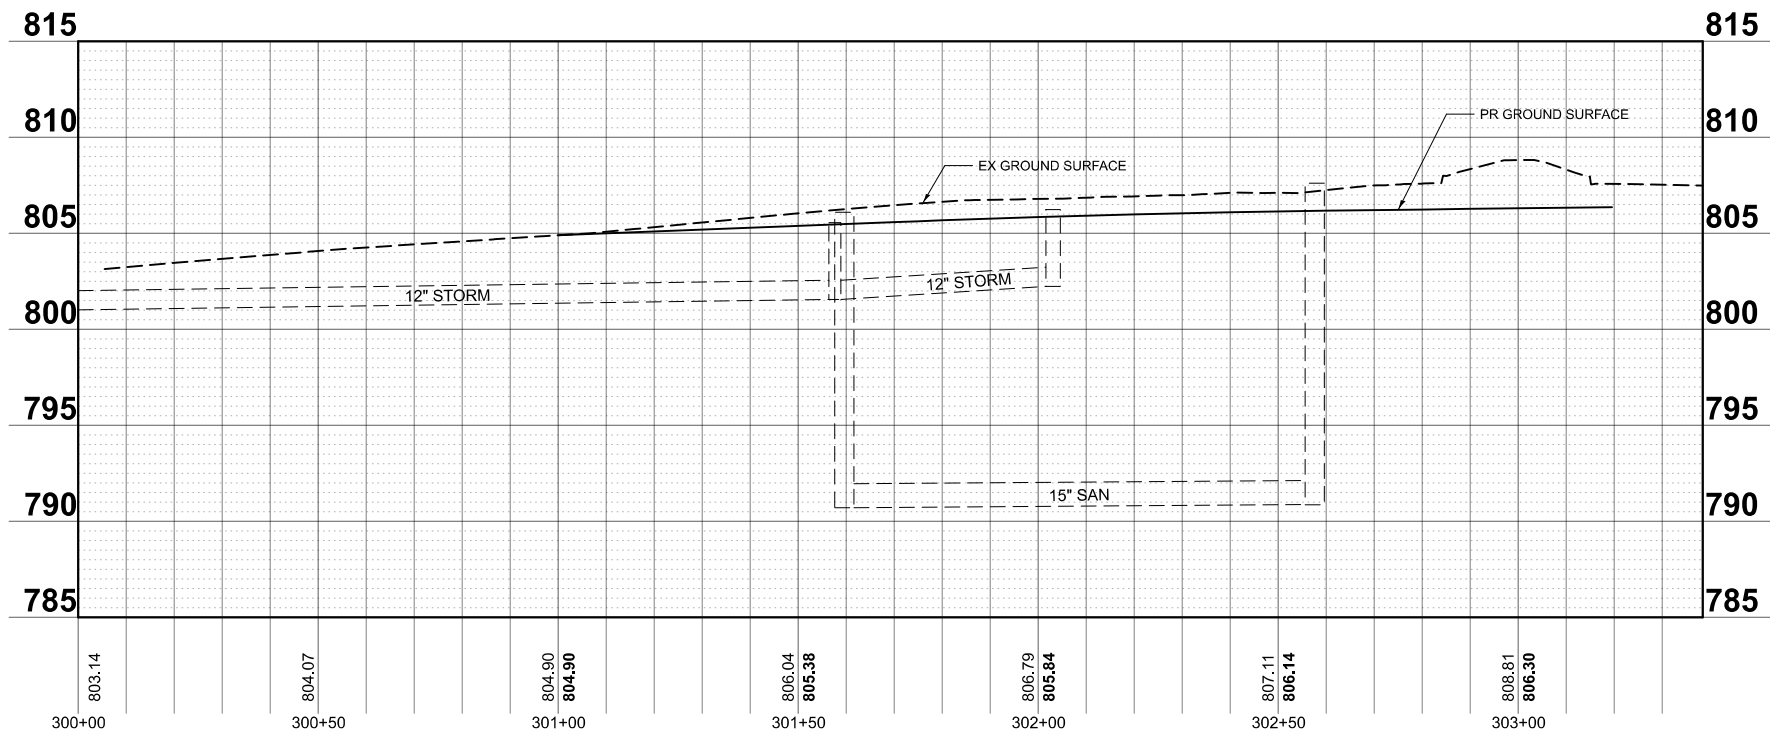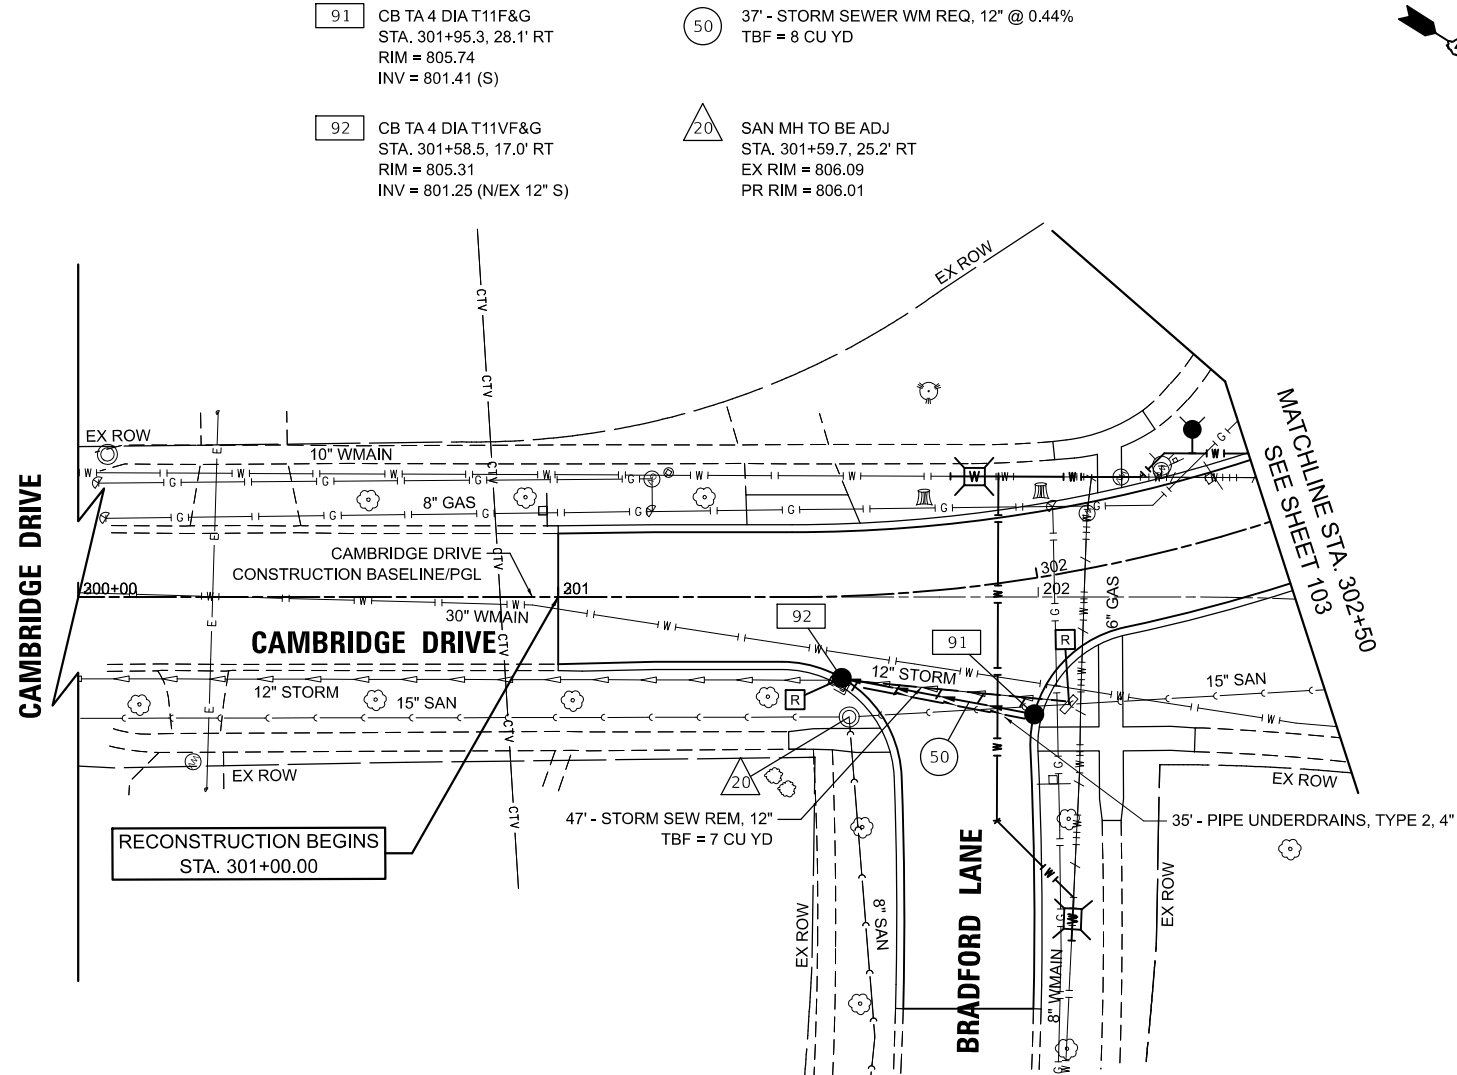

MODEL: Cambridge - Sheet 1 [Sheet]
FILE NAME: c:\bns\stltech-pw\paw\cra\k\kavets\0140565\3983.Dr\Us.dgn

USER NAME = pk	DESIGNED - EML	REVISED -
	DRAWN - EML	REVISED -
	CHECKED - TKL	REVISED -
PLOT DATE = 12/15/2025	DATE - 12/12/2025	REVISED -

STATE OF ILLINOIS
DEPARTMENT OF TRANSPORTATION

CAMBRIDGE DRIVE
DRAINAGE AND UTILITIES

SCALE: 1"=20' SHEET 14 OF 14 SHEETS STA. 300+00.00 TO STA. 302+50.00

MUN RTE.	SECTION	COUNTY	TOTAL SHEETS	SHEET NO.
4029	23-00146-00-PV	COOK	315	107
CONTRACT NO. 61M26				
ILLINOIS FED. AID PROJECT				

LEGEND

- WATER MAIN CASING PIPE
WATER MAIN CASING JACKING
SUGGESTED PIT LOCATION
STEEL CASING PIPE, BORED AND JACKED
EXISTING VALVE VAULT
EXISTING VALVE BOX
PROPOSED VALVE VAULT

NOTE:

1. MINIMUM COVER OF ALL WATER MAIN PIPES SHALL BE 5.5 FEET.
2. FOR WATER MAIN INSTALLATION AT SIDE ROAD CONNECTIONS WHERE THE EXISTING VALVE IS SHOWN TO BE REPLACED, THE TYPICAL SEQUENCE OF OPERATIONS SHALL BE AS FOLLOWS, UNLESS OTHERWISE APPROVED BY THE ENGINEER.
A. SHUT DOWN EXISTING WATER MAIN.
B. REMOVE EXISTING WATER VALVE AND VALVE VAULT / BOX, REMOVE WATER MAIN AS NEEDED TO INSTALL NEW VALVE AND CONNECTIONS, AS APPROVED BY THE ENGINEER.
C. INSTALL NEW WATER VALVE AND VALVE VAULT ON SIDE ROAD MAIN.



- D. CONNECT NEW VALVE TO EXISTING WATER MAIN TO REMAIN OUTSIDE OF VAULT.
IF THE VILLAGE DETERMINES THE NEW VALVE CAN REMAIN CLOSED, THEN:

- A. INSTALL SECTION OF WATER MAIN TOWARDS BRAINTREE WATER MAIN OUTSIDE OF VALVE VAULT. TEMPORARILY CAP AND THRUST BLOCK.
B. TEMPORARILY CAP AND THRUST BLOCK EXISTING BRAINTREE MAIN.
C. CLOSE NEW VALVE AND OPEN EXISTING VALVES.

INSTALLATION AND REMOVAL OF TEMPORARY CAPS AND THRUST BLOCKS SHALL BE INCLUDED IN THE COST OF "CONNECTION TO EXISTING WATERMAIN".

3. PRIOR TO THE START OF WATERMAIN CONSTRUCTION, THE CONTRACTOR SHALL DETERMINE IF THE EXISTING TRANSMISSION MAIN AND THE DISTRIBUTION MAINS ARE CONNECTED (PAID FOR AS EXPLORATION TRENCH (SPECIAL). IF THE MAINS ARE CONNECTED, THE CONTRACTOR SHALL COORDINATE WITH THE VILLAGE AND ENGINEER TO DETERMINE IF RECONNECTION IS REQUIRED, AND IF SO, CONFIGURATION OF RECONNECTION.

4. EXISTING TRAFFIC SIGNAL CONDUIT AND CABLE SHALL REMAIN IN PLACE. CONTRACTOR SHALL WATCH AND PROTECT IN ACCORDANCE WITH THE ARTICLE 107.39 OF THE STANDARD SPECIFICATIONS.

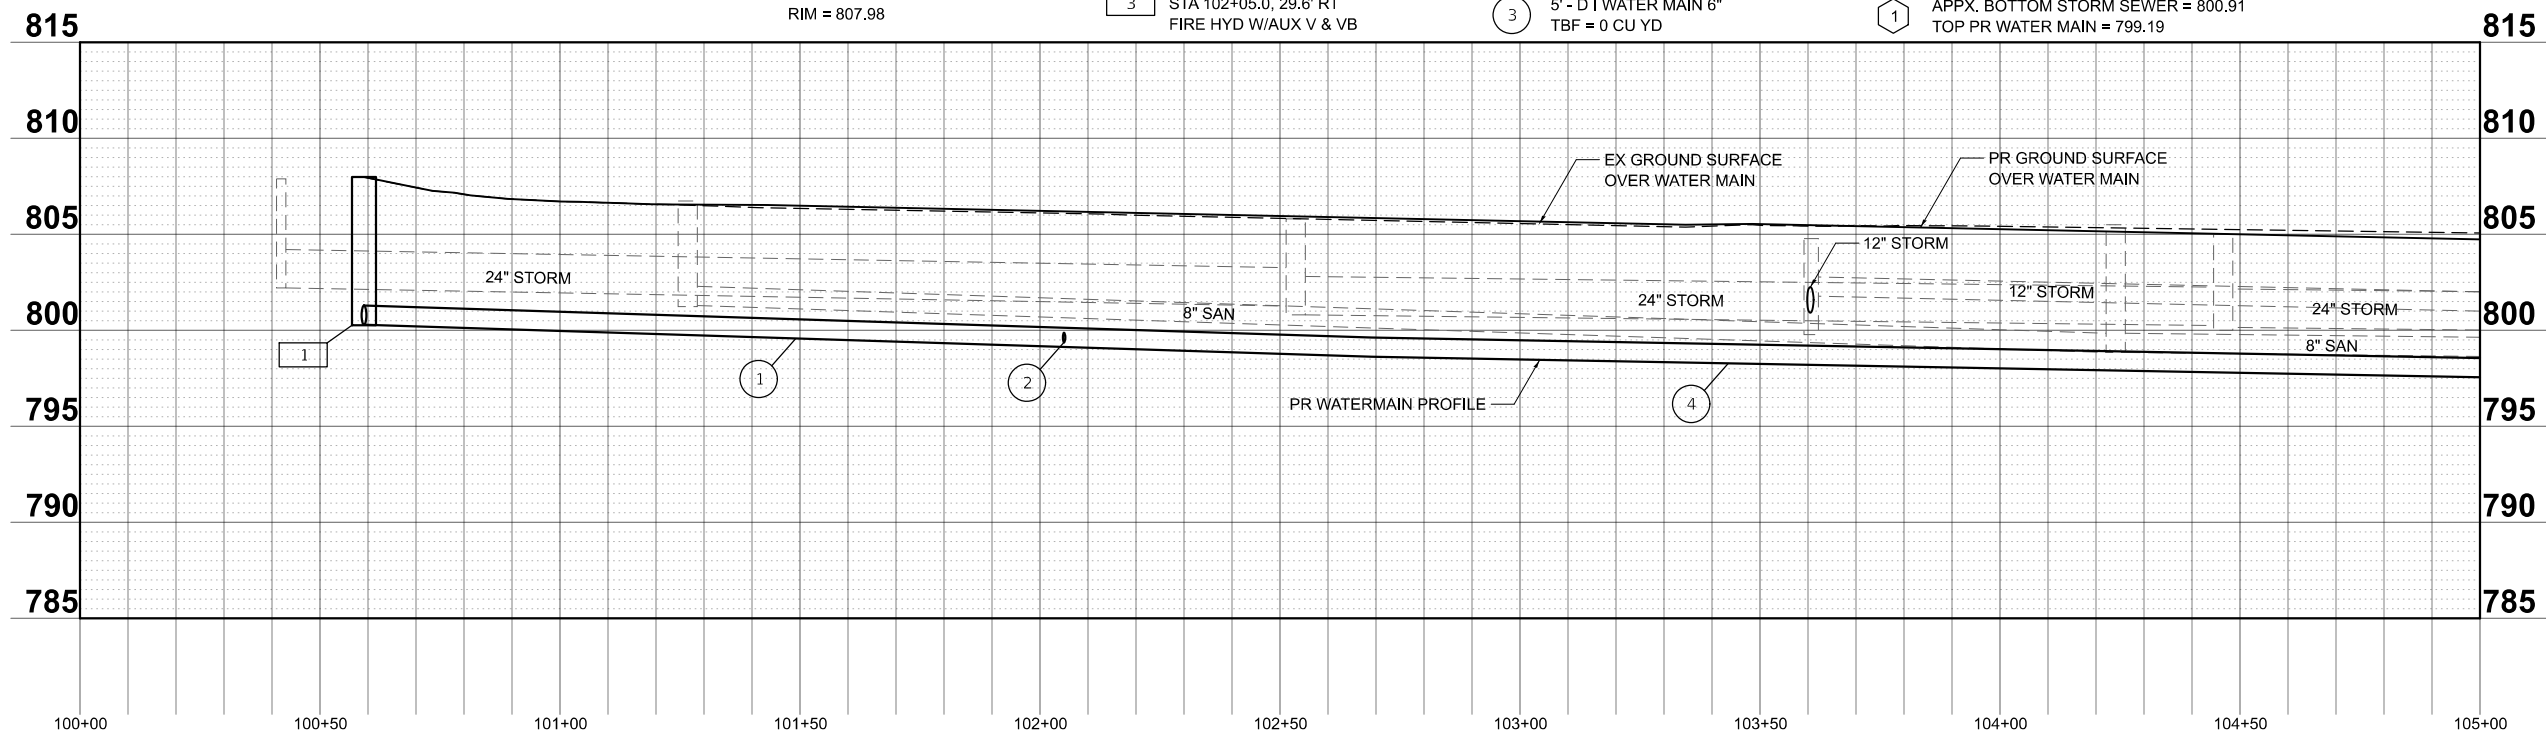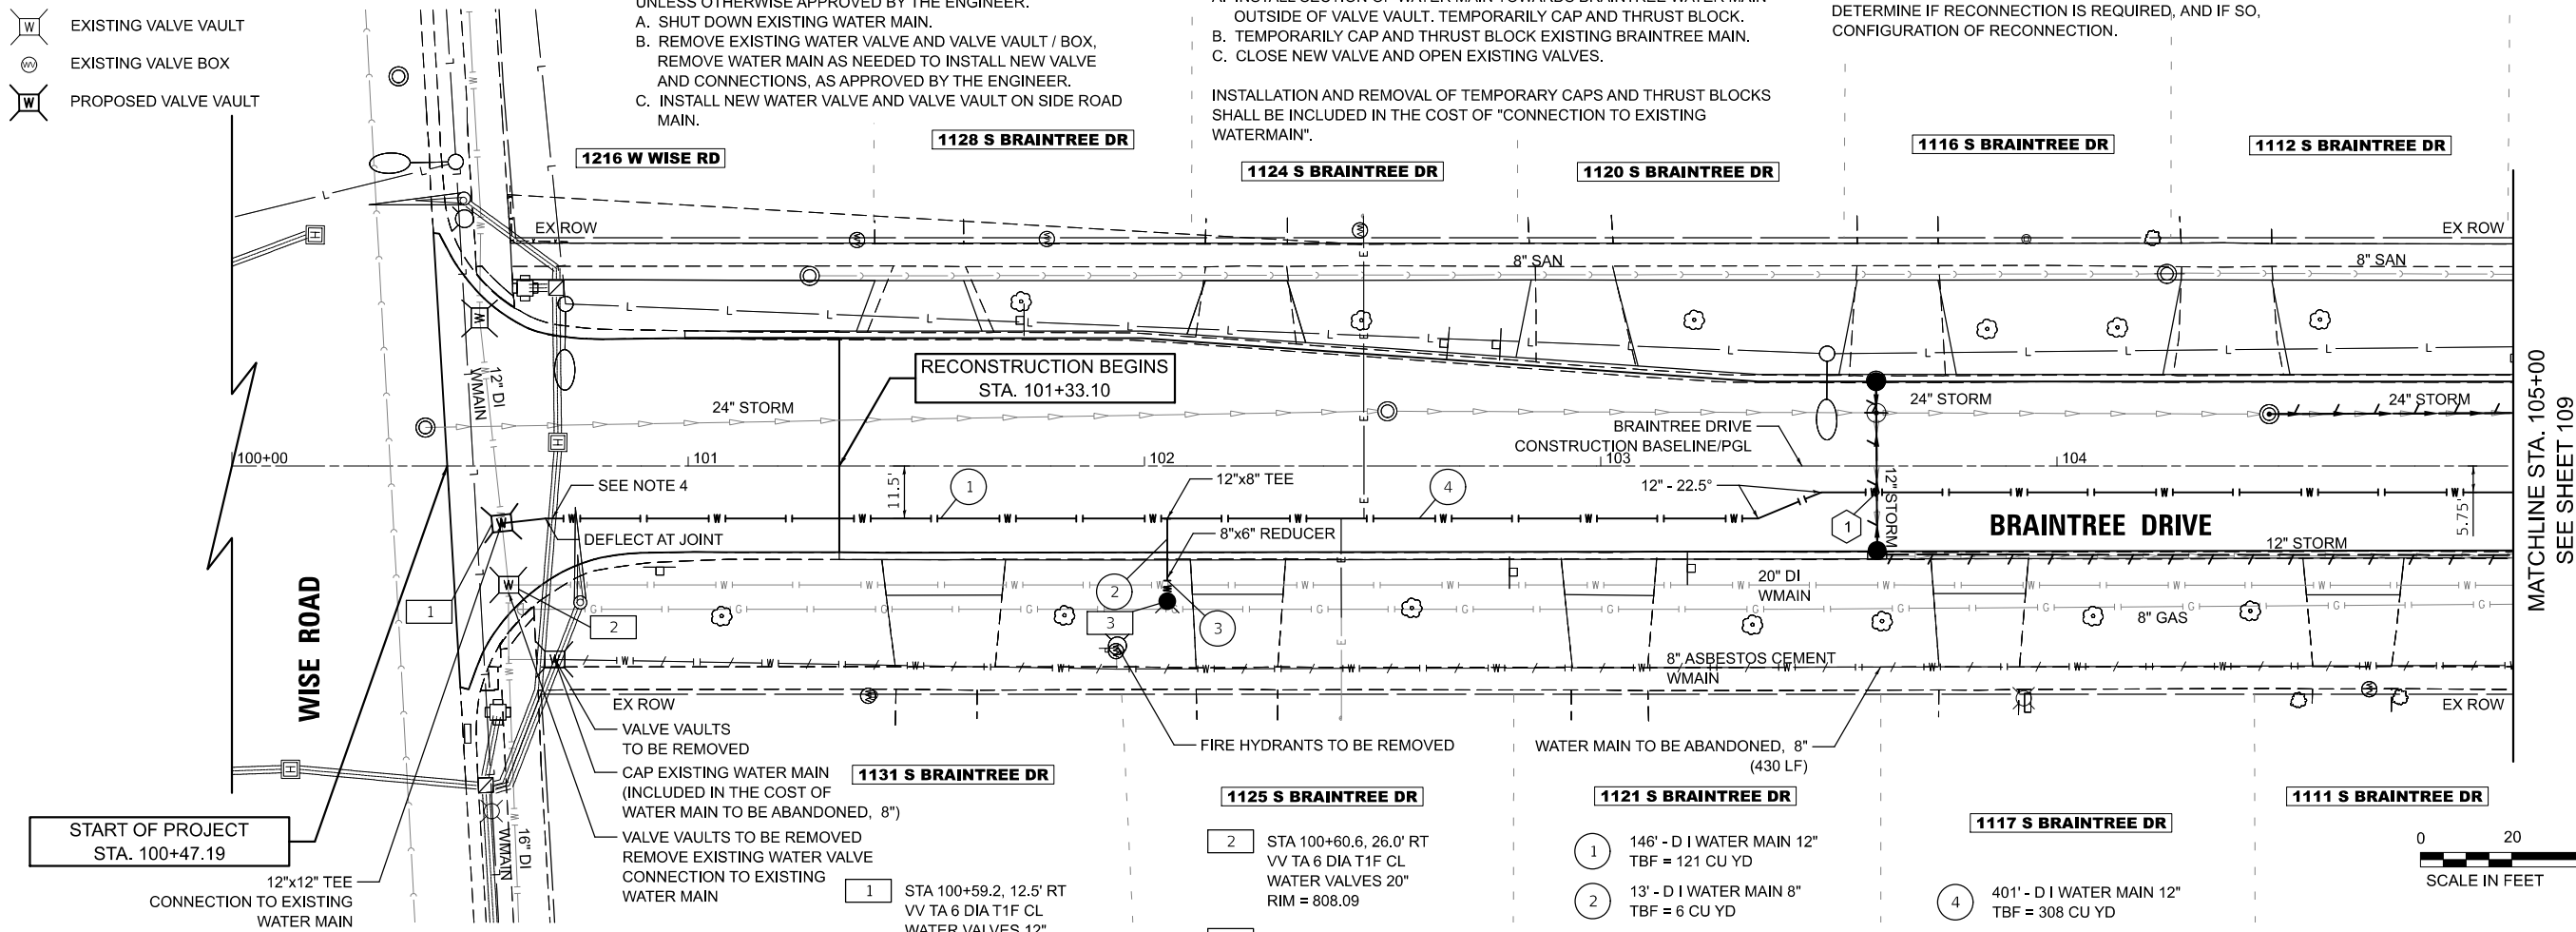

MODEL: Braintree - Sheet 1 [Sheet]
FILE NAME: c:\bms\chilich-p\p\pairo.kravets\0140565\3983.Watermain.dgn

USER NAME = pk	DESIGNED - AMP	REVISED -
	DRAWN - AMP	REVISED -
	CHECKED - PK	REVISED -
PLOT DATE = 1/7/2026	DATE - 01/07/2026	REVISED -

STATE OF ILLINOIS
DEPARTMENT OF TRANSPORTATION

BRAINTREE DRIVE
WATER MAIN PLAN AND PROFILE

SCALE: 1"=20' SHEET 1 OF 14 SHEETS STA. 100+00.00 TO STA. 105+00.00

MUN RTE.	SECTION	COUNTY	TOTAL SHEETS	SHEET NO.
4029	23-00146-00-PV	COOK	315	108
CONTRACT NO. 61M26				
ILLINOIS FED. AID PROJECT				

LEGEND


- WATER MAIN CASING PIPE
WATER MAIN CASING JACKING
SUGGESTED PIT LOCATION
STEEL CASING PIPE, BORED AND JACKED
EXISTING VALVE VAULT
EXISTING VALVE BOX
PROPOSED VALVE VAULT

- 4 STA 106+05.0, 36.2' RT
FIRE HYD W/AUX V & VB
5 STA 106+83.9, 61.5' LT
VV TA 6 DIA T1F CL
WATER VALVES 8"
RIM = 803.92
6 STA 108+00.0, 11.5' LT
VV TA 6 DIA T1F CL
WATER VALVES 12"
RIM = 804.22

- 4 SEE SHEET 108
5 25' - D I WATER MAIN 8"
TBF = 10 CU YD
6 5' - D I WATER MAIN 6"
TBF = 0 CU YD


- 7 79' - D I WATER MAIN 12"
TBF = 64 CU YD
8 68' - D I WATER MAIN 8"
TBF = 35 CU YD
9 5' - D I WATER MAIN 8"
TBF = 0 CU YD
10 124' - D I WATER MAIN 12"
TBF = 98 CU YD
11 170' - D I WATER MAIN 12"
TBF = 131 CU YD

- 2 APPX. BOTTOM STORM SEWER = 799.57
TOP PR WATER MAIN = 798.03
3 APPX. BOTTOM SANITARY SEWER = 798.37
TOP PR WATER MAIN CASING = 796.87

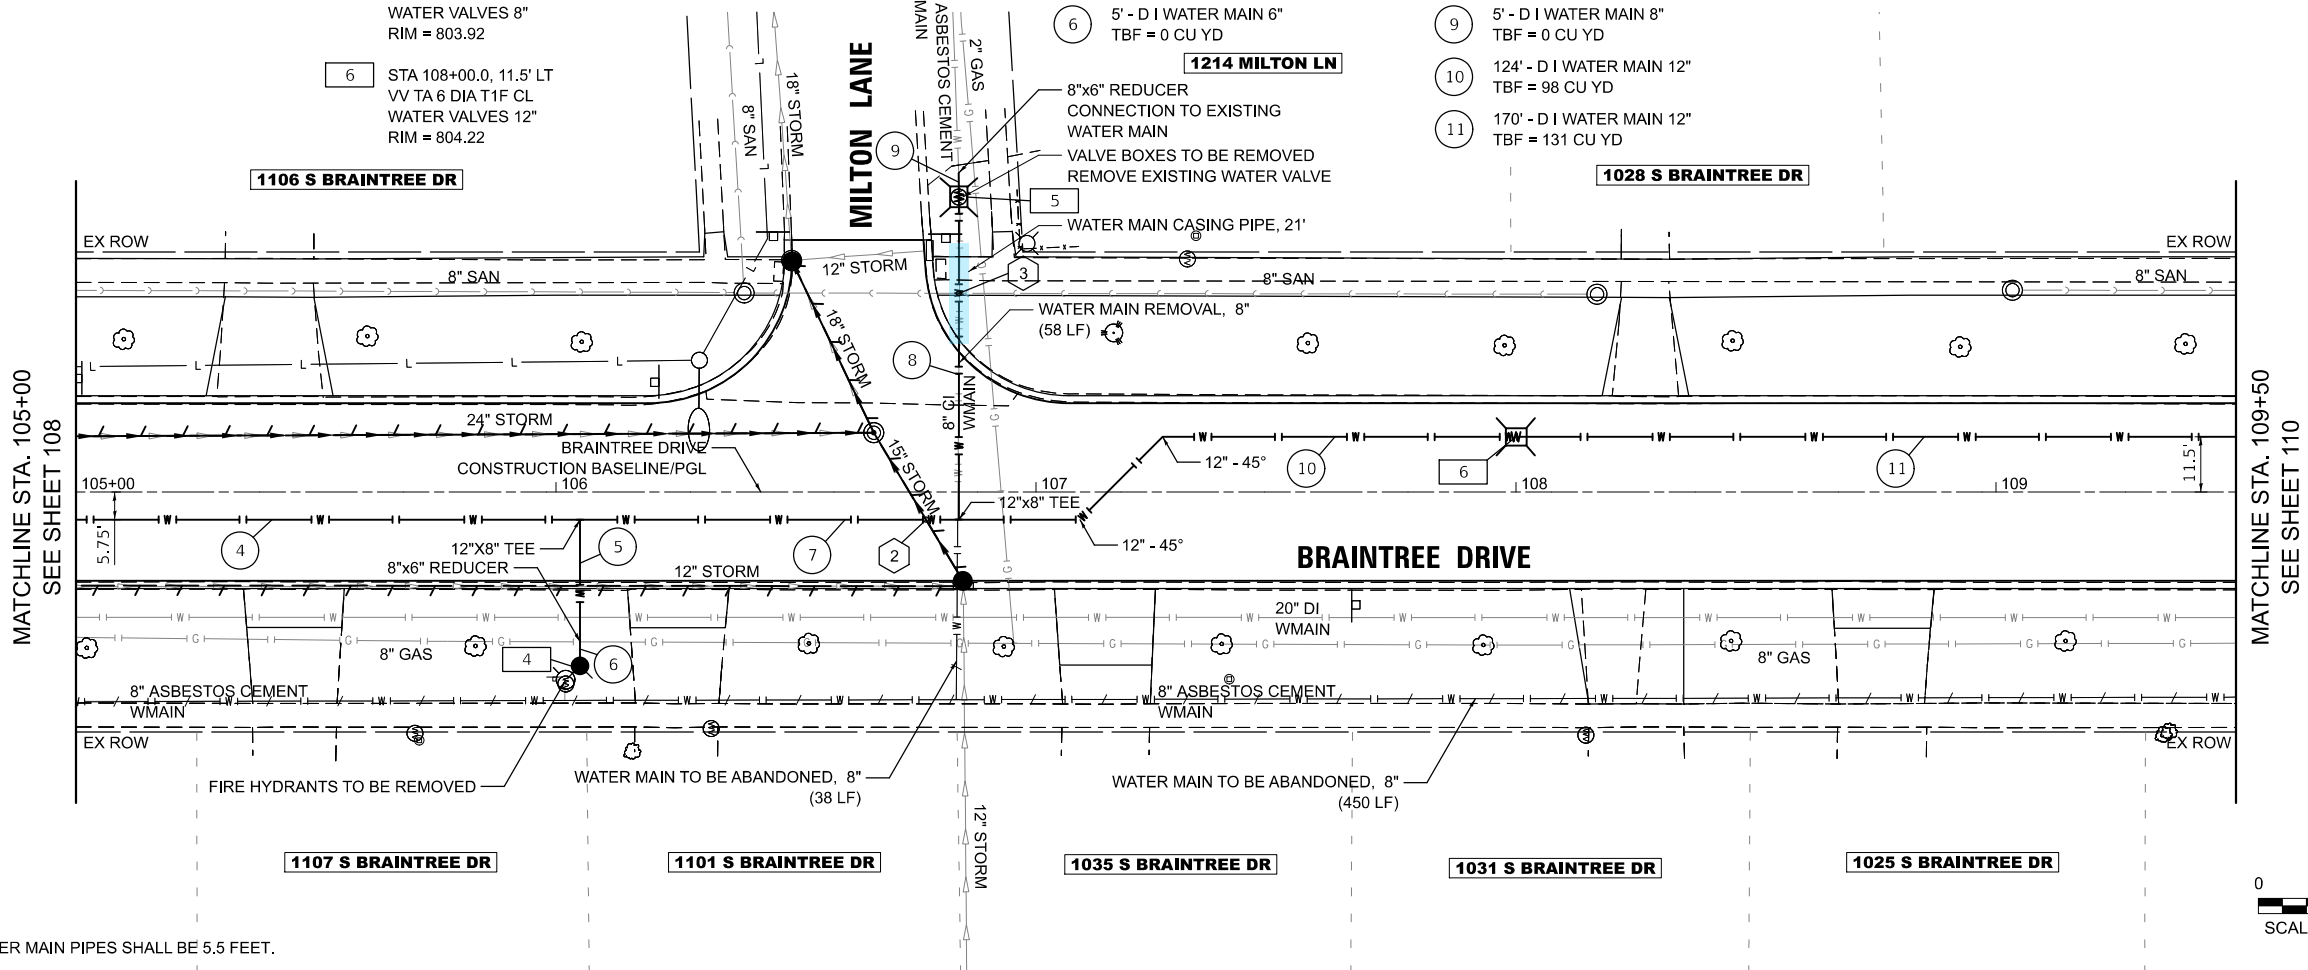

NOTE:

1. MINIMUM COVER OF ALL WATER MAIN PIPES SHALL BE 5.5 FEET.

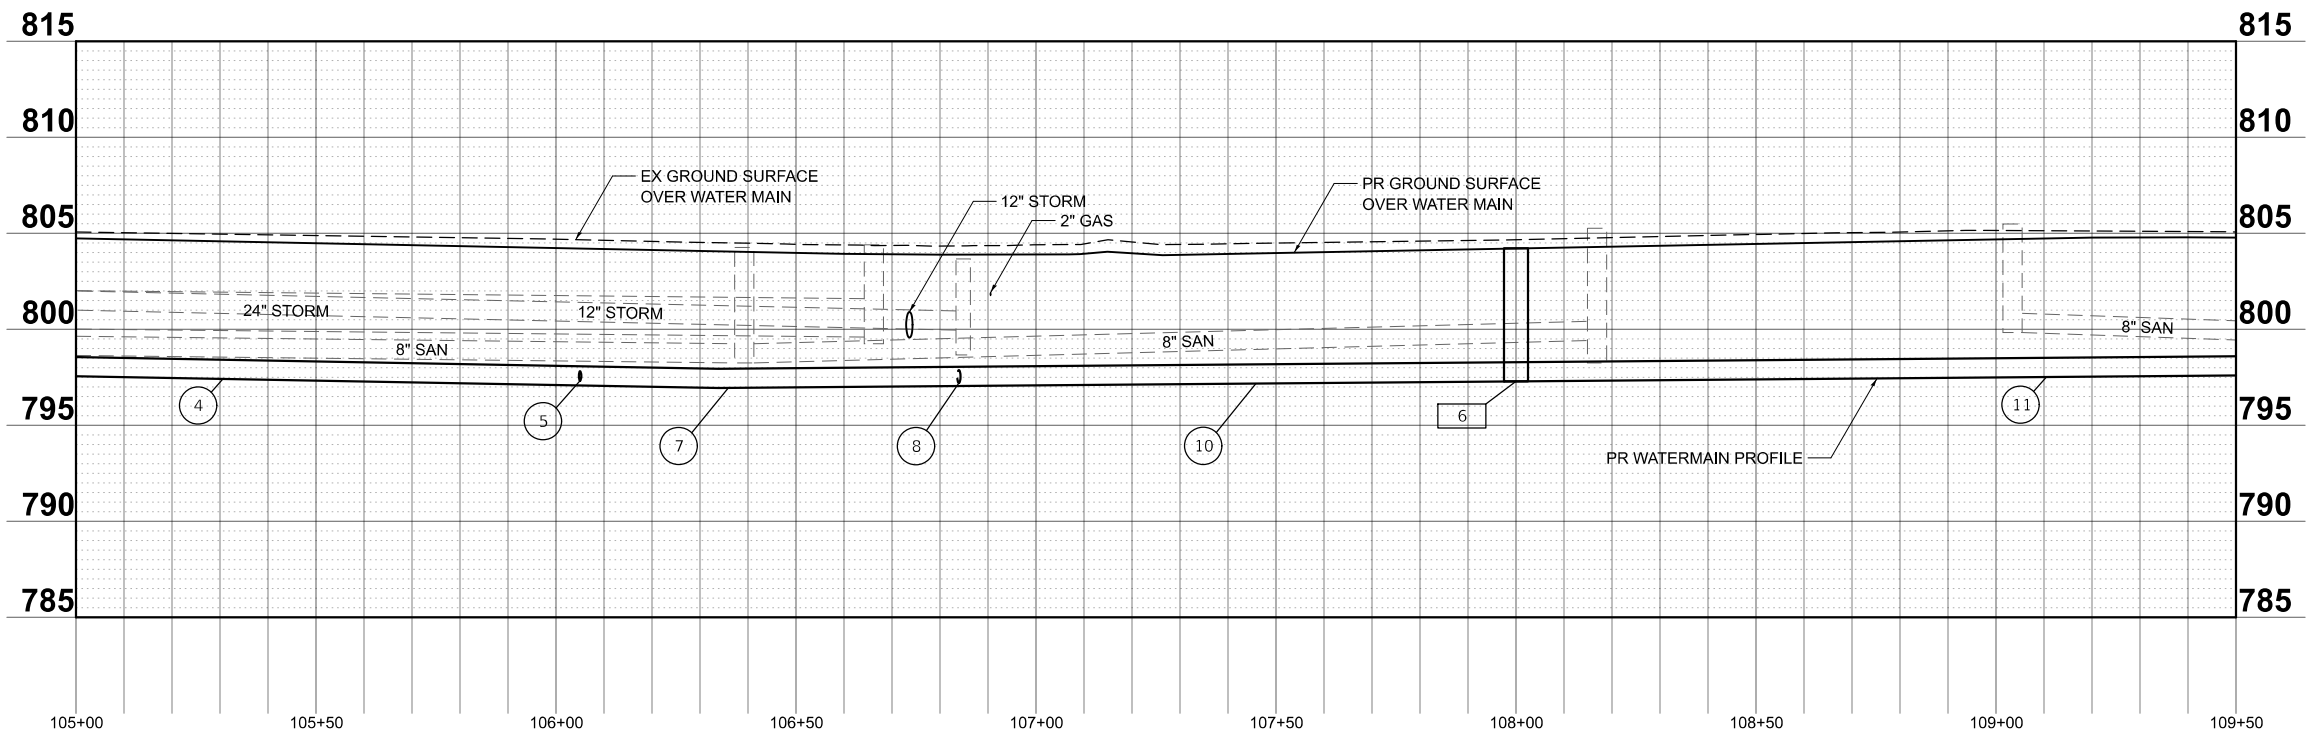

MODEL: Braintree - Sheet 2 (Sheet)
FILE NAME: c:\bms\sch\tech-pw\pairo.kravets\0140565\3983.Watermain.dgn

USER NAME = pk	DESIGNED - AMP	REVISED -
	DRAWN - AMP	REVISED -
	CHECKED - PK	REVISED -
PLOT DATE = 1/7/2026	DATE - 01/07/2026	REVISED -

STATE OF ILLINOIS
DEPARTMENT OF TRANSPORTATION

BRAINTREE DRIVE
WATER MAIN PLAN AND PROFILE

SCALE: 1"=20' SHEET 2 OF 14 SHEETS STA. 105+00.00 TO STA. 109+50.00

MUN. RTE.	SECTION	COUNTY	TOTAL SHEETS	SHEET NO.
4029	23-00146-00-PV	COOK	315	109
CONTRACT NO. 61M26				
ILLINOIS FED. AID PROJECT				

LEGEND

- WATER MAIN CASING PIPE
- WATER MAIN CASING JACKING SUGGESTED PIT LOCATION
- STEEL CASING PIPE, BORED AND JACKED
- EXISTING VALVE VAULT
- EXISTING VALVE BOX
- PROPOSED VALVE VAULT

- 7 STA 109+70.0, 30.3' LT FIRE HYD W/AUX V & VB (SEE NOTE 2)
- 8 STA 110+13.2, 27.2' RT VV TA 6 DIA T1F CL WATER VALVES 20" RIM = 804.78
- 9 STA 110+37.2, 63.6' LT VV TA 5 DIA T1F CL WATER VALVES 8" RIM = 804.54



- 10 STA 113+00.0, 30.2' LT FIRE HYD W/AUX V & VB
- 11 STA 113+35.8, 11.5' RT VV TA 6 DIA T1F CL WATER VALVES 12" RIM = 801.32
- 12 STA 114+13.5, 55.6' RT VV TA 6 DIA T1F CL WATER VALVES 12" RIM = 802.16

- 11 SEE SHEET 109
- 12 14' - D I WATER MAIN 8" TBF = 7 CU YD
- 13 5' - D I WATER MAIN 6" TBF = 0 CU YD
- 14 68' - D I WATER MAIN 12" TBF = 54 CU YD
- 15 53' - D I WATER MAIN 8" TBF = 26 CU YD
- 16 5' - D I WATER MAIN 8" TBF = 4 CU YD

- 17 263' - D I WATER MAIN 12" TBF = 212 CU YD
- 18 14' - D I WATER MAIN 8" TBF = 7 CU YD
- 19 5' - D I WATER MAIN 6" TBF = 0 CU YD
- 20 36' - D I WATER MAIN 12" TBF = 30 CU YD
- 21 23' - D I WATER MAIN 12" TBF = 23 CU YD
- 22 12' - D I WATER MAIN 12" TBF = 12 CU YD

- 23 78' - D I WATER MAIN 12" TBF = 59 CU YD
- 24 67' - D I WATER MAIN 12" TBF = 33 CU YD
- 25 5' - D I WATER MAIN 12" TBF = 0 CU YD
- 26 136' - D I WATER MAIN 12" TBF = 105 CU YD

- 4 APPX. BOTTOM SANITARY SEWER = 798.63 TOP PR WATER MAIN CASING = 797.13
- 5 APPX. BOTTOM STORM SEWER = 796.48 TOP PR WATER MAIN = 794.70

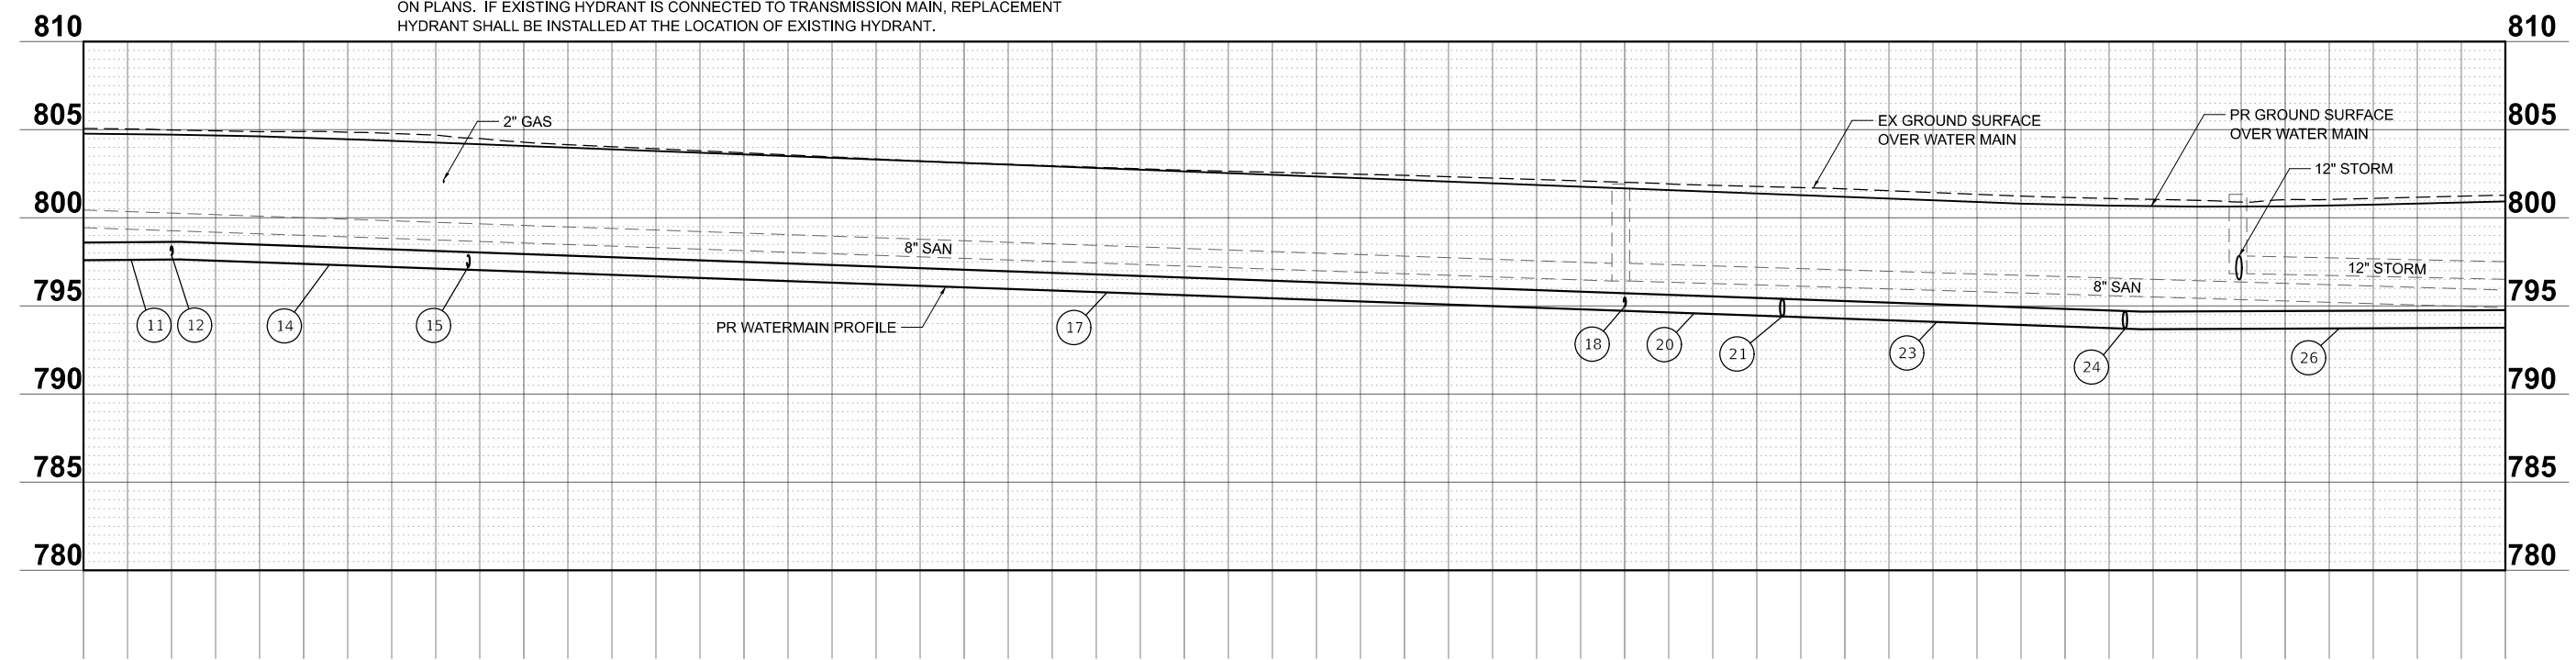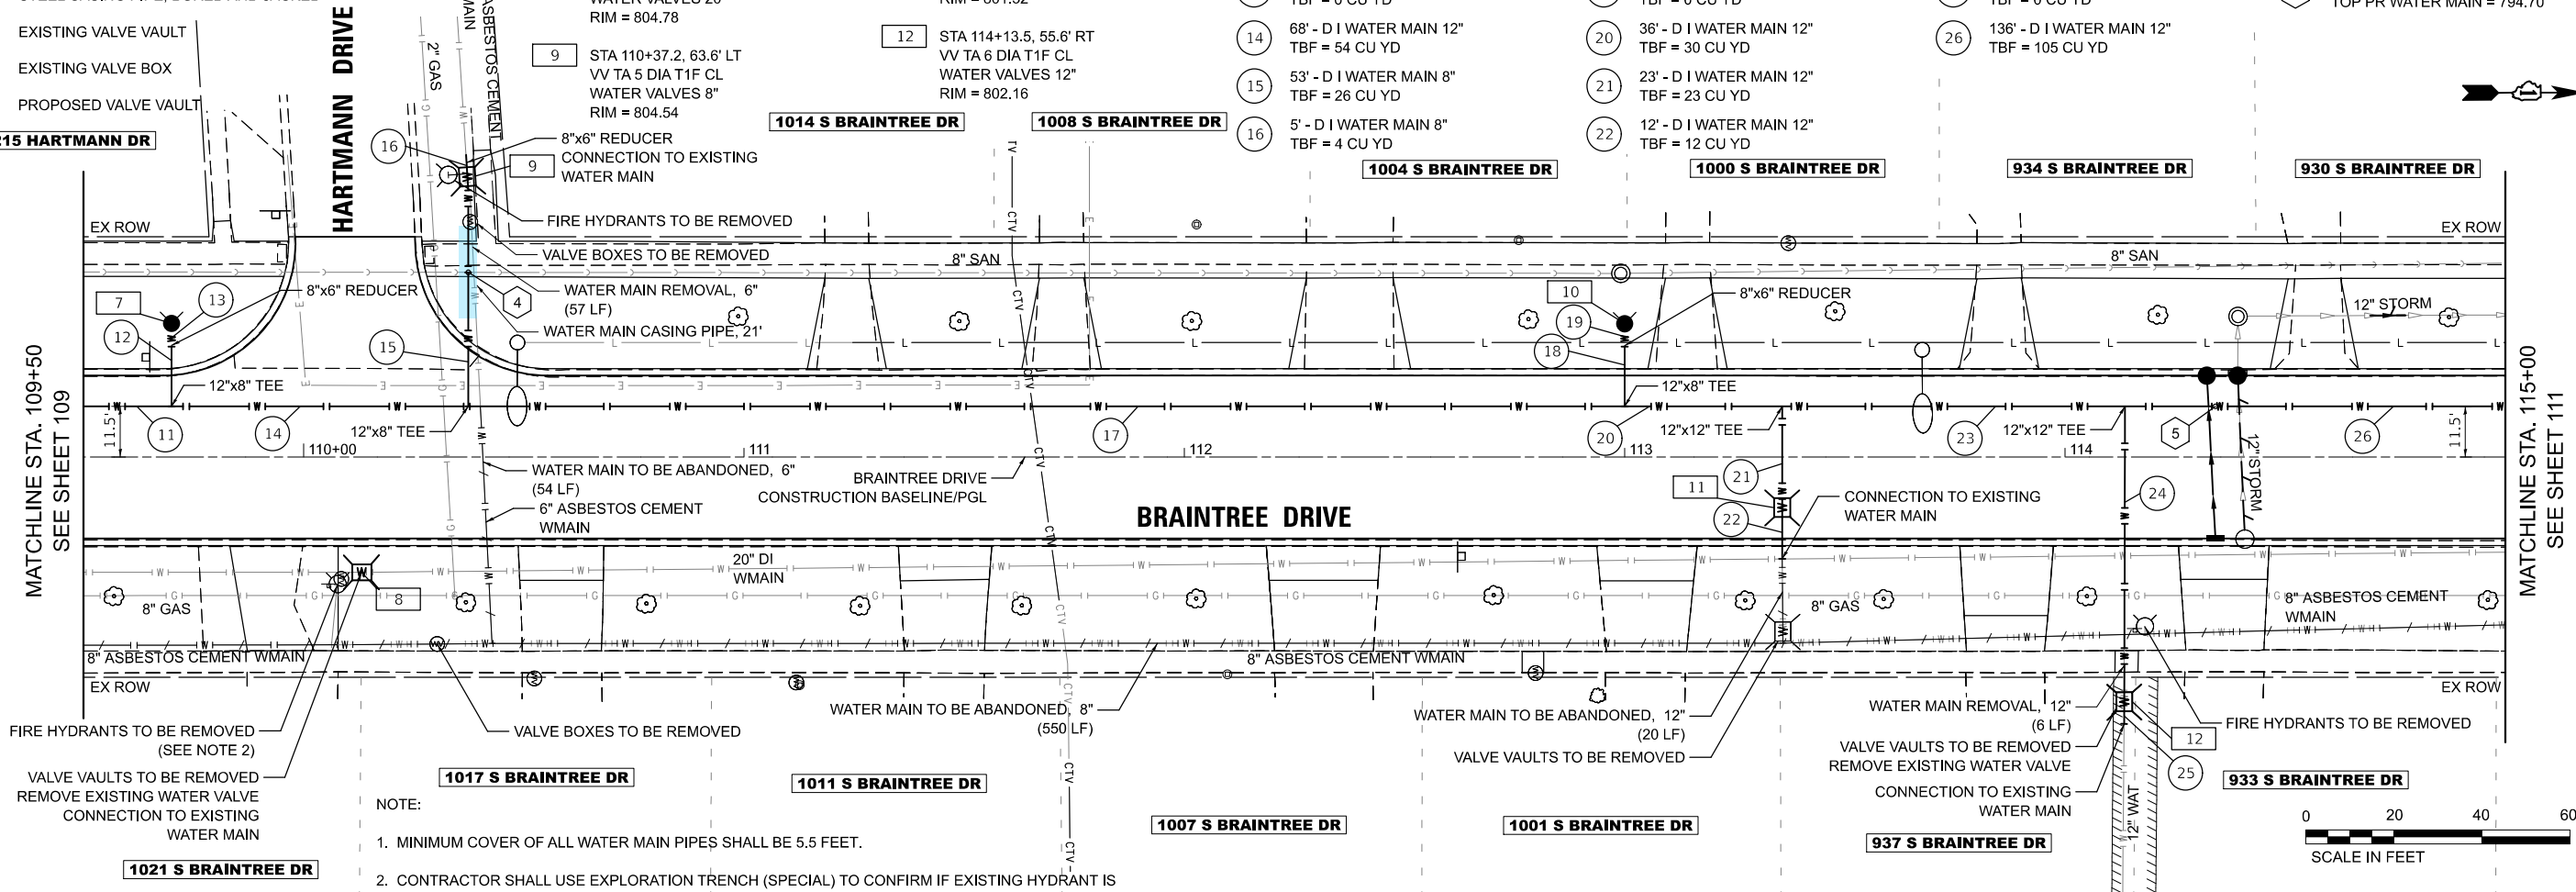

PLOT DATE = 1/7/2026	USER NAME = pk	DESIGNED - AMP	REVISED -
		DRAWN - AMP	REVISED -
		CHECKED - PK	REVISED -
		DATE - 01/07/2026	REVISED -

STATE OF ILLINOIS
DEPARTMENT OF TRANSPORTATION

BRAINTREE DRIVE
WATER MAIN PLAN AND PROFILE

SCALE: 1"=20' SHEET 3 OF 14 SHEETS STA. 109+50.00 TO STA. 115+00.00

MUN RTE.	SECTION	COUNTY	TOTAL SHEETS	SHEET NO.
4029	23-00146-00-PV	COOK	315	110
CONTRACT NO. 61M26				
ILLINOIS FED. AID PROJECT				

LEGEND

- WATER MAIN CASING PIPE
WATER MAIN CASING JACKING
SUGGESTED PIT LOCATION
STEEL CASING PIPE, BORED AND JACKED
EXISTING VALVE VAULT
EXISTING VALVE BOX
PROPOSED VALVE VAULT

13 STA 115+50.0, 11.5' LT
VV TA 6 DIA T1F CL
WATER VALVES 12"
RIM = 801.00

14 STA 116+70.0, 30.7' LT
FIRE HYD W/AUX V & VB

15 STA 117+92.8, 23.3' RT
VV TA 6 DIA T1F CL
WATER VALVES 20"
RIM = 800.28

16 STA 118+72.4, 23.6' RT
VV TA 6 DIA T1F CL
WATER VALVES 20"
RIM = 799.95

26 SEE SHEET 110


27 119' - D I WATER MAIN 12"
TBF = 96 CU YD

28 14' - D I WATER MAIN 8"
TBF = 7 CU YD

29 5' - D I WATER MAIN 6"
TBF = 0 CU YD


30 348' - D I WATER MAIN 12"
TBF = 274 CU YD

6 APPX. BOTTOM STORM SEWER = 795.49
TOP PR WATER MAIN = 793.77

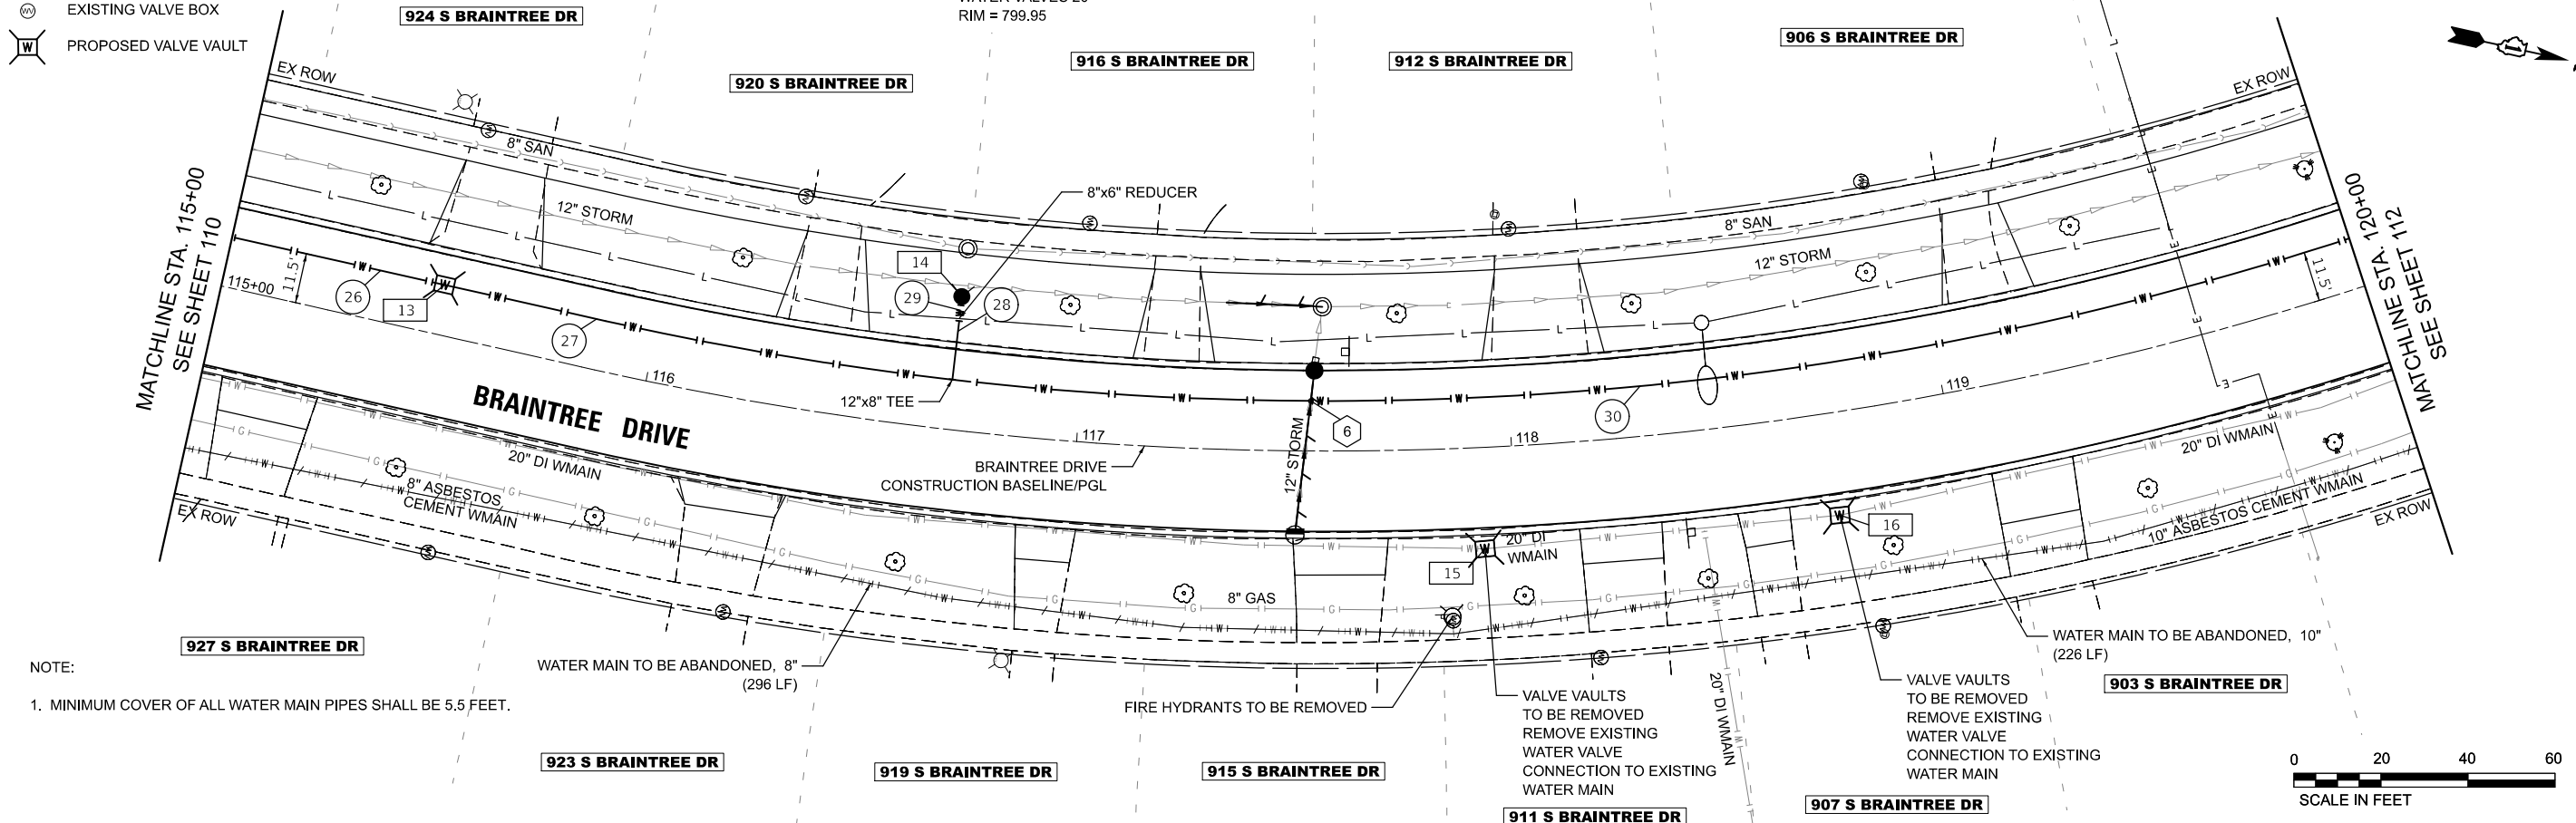

NOTE:

1. MINIMUM COVER OF ALL WATER MAIN PIPES SHALL BE 5.5 FEET.

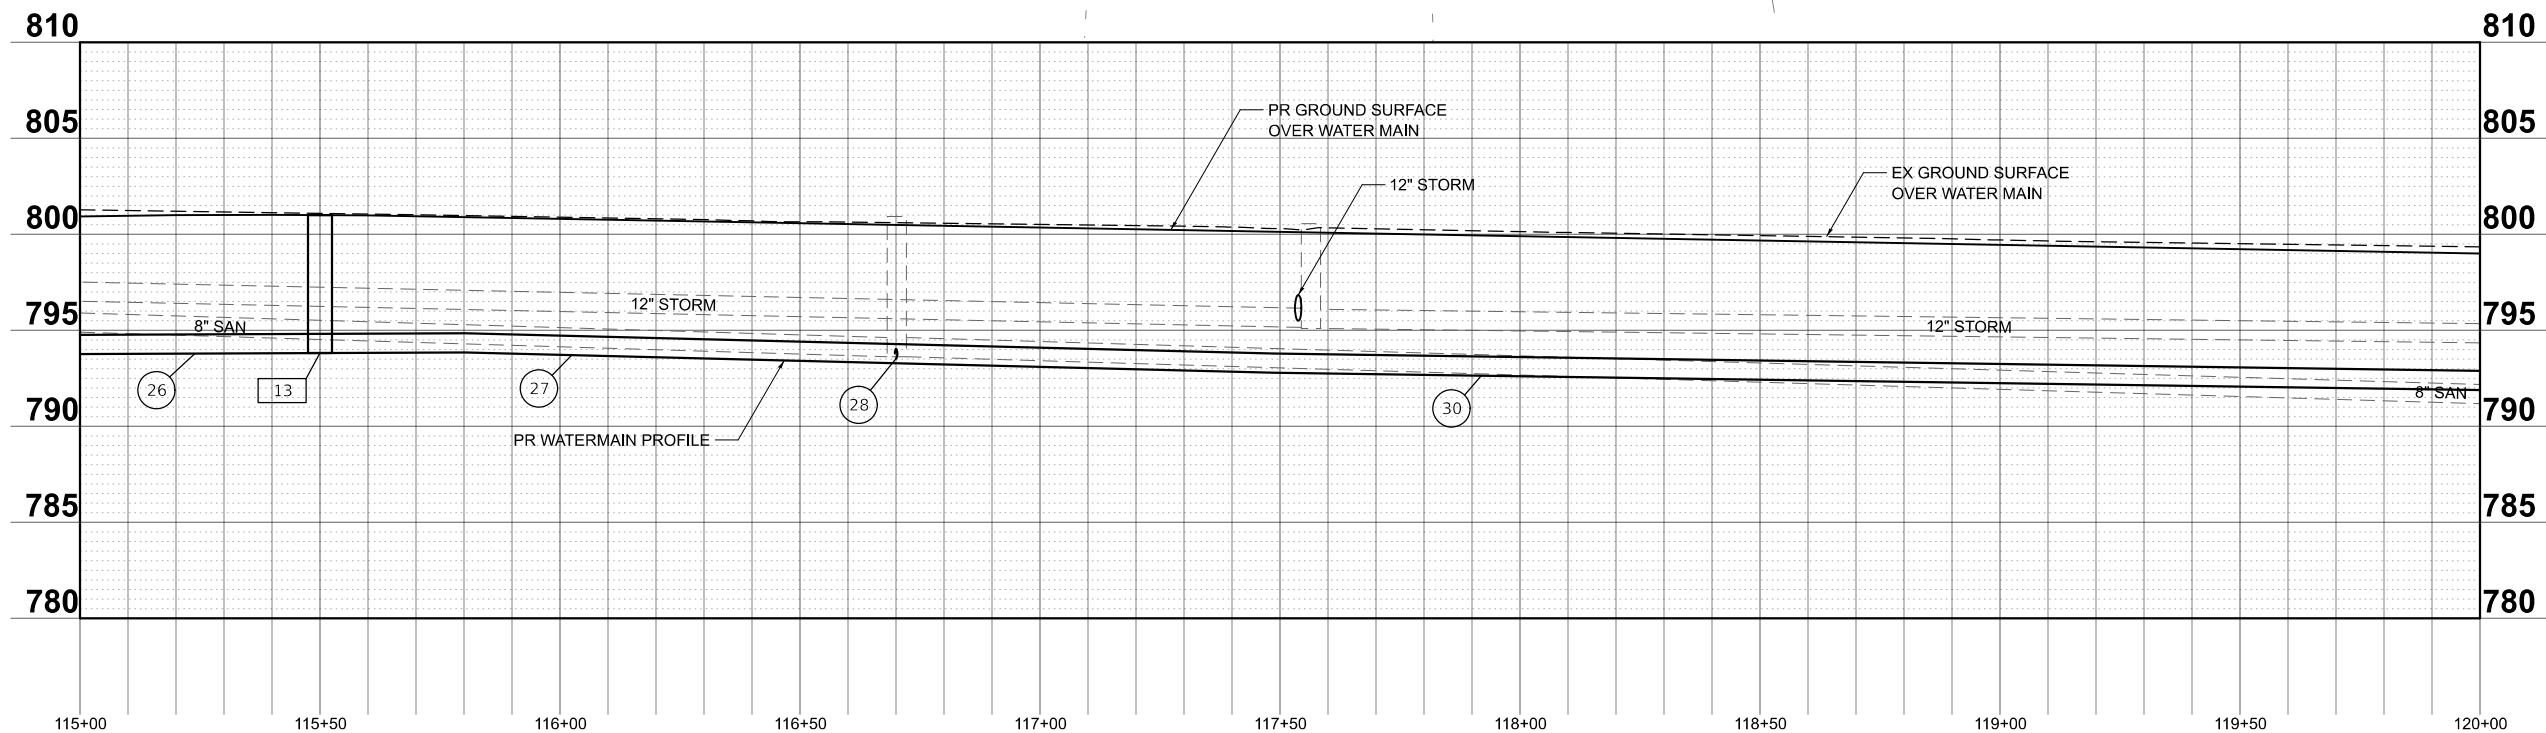

MODEL: Braintree - Sheet 4 [Sheet]
FILE NAME: c:\bms\schlitch-pw\pairo.kravets\0140565\3983.Watermain.dgn

USER NAME = pk	DESIGNED - AMP	REVISED -
	DRAWN - AMP	REVISED -
	CHECKED - PK	REVISED -
PLOT DATE = 1/7/2026	DATE - 01/07/2026	REVISED -

STATE OF ILLINOIS
DEPARTMENT OF TRANSPORTATION

BRAINTREE DRIVE
WATER MAIN PLAN AND PROFILE

SCALE: 1"=20' SHEET 4 OF 14 SHEETS STA. 115+00.00 TO STA. 120+00.00

MUN RTE.	SECTION	COUNTY	TOTAL SHEETS	SHEET NO.
4029	23-00146-00-PV	COOK	315	111
CONTRACT NO. 61M26				
ILLINOIS FED. AID PROJECT				

LEGEND

- WATER MAIN CASING PIPE
WATER MAIN CASING JACKING
SUGGESTED PIT LOCATION
STEEL CASING PIPE, BORED AND JACKED
EXISTING VALVE VAULT
EXISTING VALVE BOX
PROPOSED VALVE VAULT

17 STA 120+23.1, 26.7' LT
FIRE HYD W/AUX V & VB
18 STA 121+30.8, 25.4' RT
VV TA 6 DIA T1F CL
WATER VALVES 20"
RIM = 798.40

19 STA 121+32.3, 53.1' RT
VV TA 5 DIA T1F CL
WATER VALVES 8"
RIM = 798.80

20 STA 121+37.2, 55.2' LT
VV TA 5 DIA T1F CL
WATER VALVES 8"
RIM = 799.29

21 STA 123+48.0, 31.5' LT
FIRE HYD W/AUX V & VB

22 STA 124+01.8, 5.8' LT
VV TA 6 DIA T1F CL
WATER VALVES 12"
RIM = 800.52

30 SEE SHEET 111

31 10' - D I WATER MAIN 8"
TBF = 7 CU YD

32 5' - D I WATER MAIN 6"
TBF = 0 CU YD

33 140' - D I WATER MAIN 12"
TBF = 108 CU YD

34 55' - D I WATER MAIN 8"
TBF = 24 CU YD

35 5' - D I WATER MAIN 8"
TBF = 0 CU YD

36 47' - D I WATER MAIN 12"
TBF = 23 CU YD

37 18' - D I WATER MAIN 20"
TBF = 9 CU YD

38 32' - D I WATER MAIN 8"
TBF = 17 CU YD

39 5' - D I WATER MAIN 8"
TBF = 0 CU YD

40 184' - D I WATER MAIN 12"
TBF = 148 CU YD

41 24' - D I WATER MAIN 8"
TBF = 11 CU YD


42 2' - D I WATER MAIN 6"
TBF = 0 CU YD

43 55' - D I WATER MAIN 12"
TBF = 49 CU YD

44 145' - D I WATER MAIN 12"
TBF = 133 CU YD

NOTE:

1. MINIMUM COVER OF ALL WATER MAIN PIPES SHALL BE 5.5 FEET.

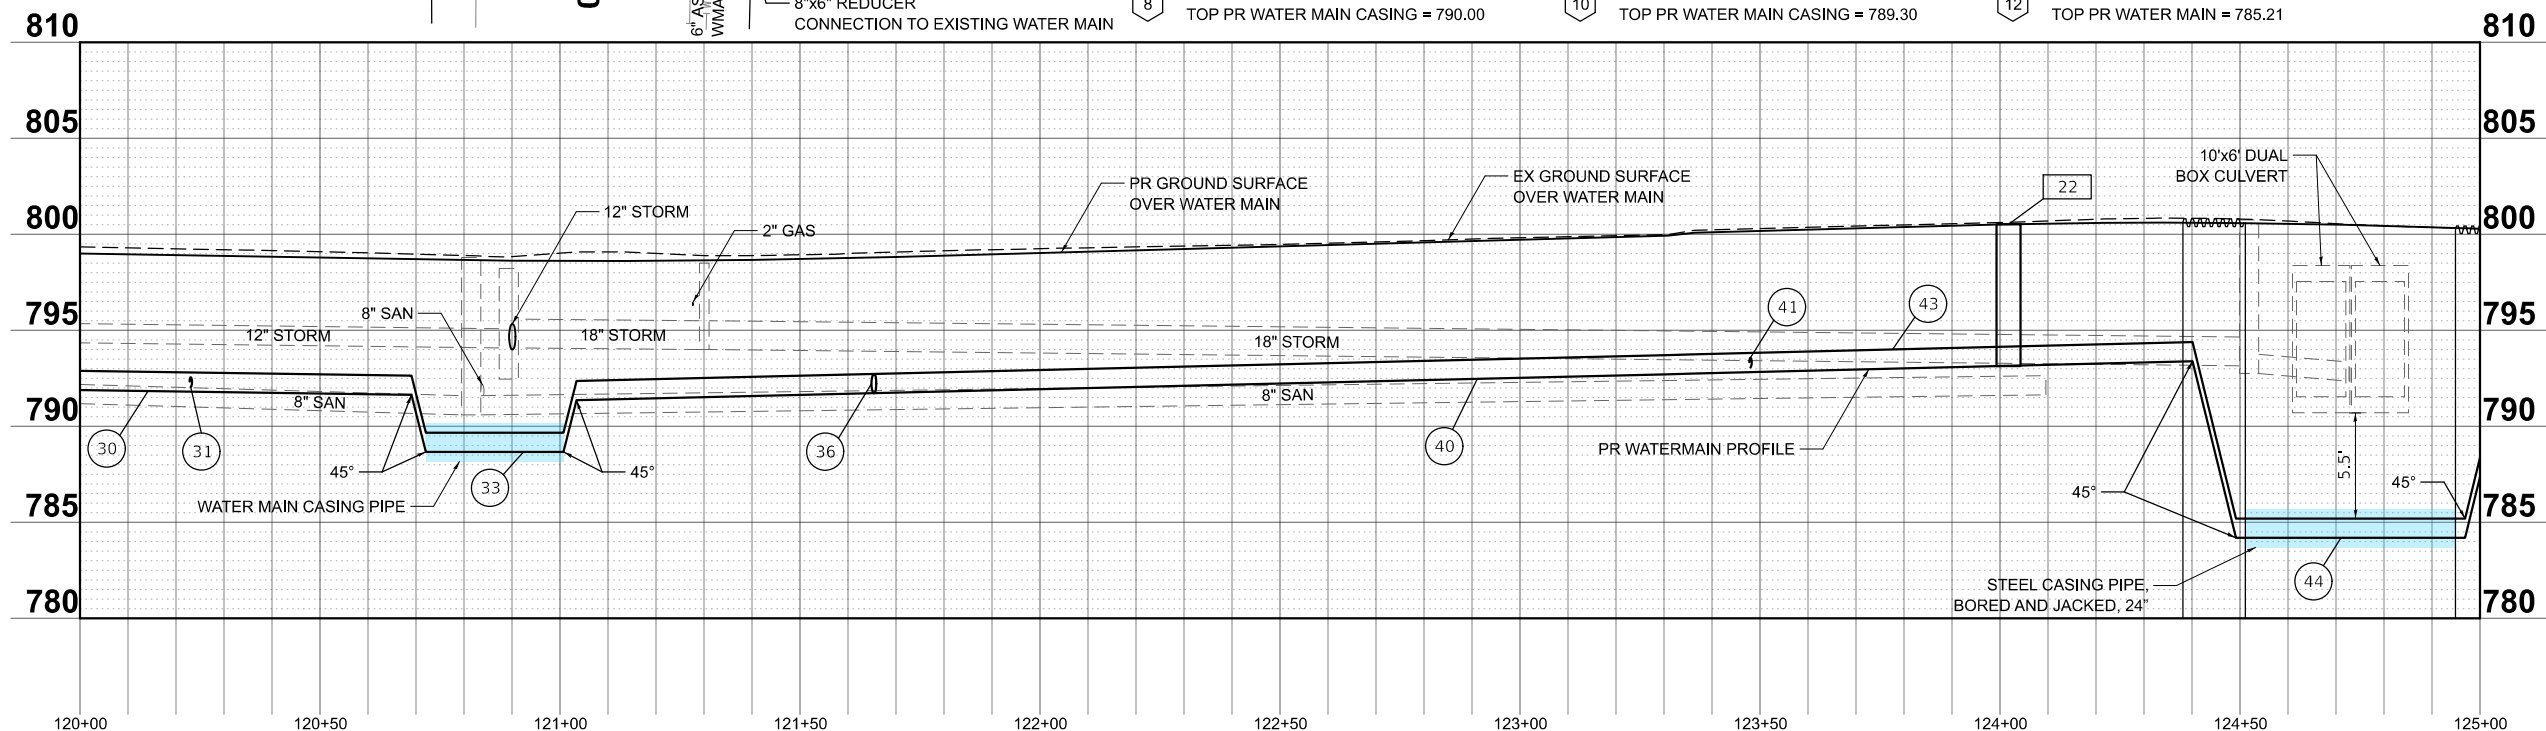

MODEL: Braintree - Sheet 5 [Sheet]
FILE NAME: c:\bns\dwg\tech-pw\pairo.kravets\014056513983.Watermain.dgn

USER NAME = pk	DESIGNED - AMP	REVISED -
	DRAWN - AMP	REVISED -
	CHECKED - PK	REVISED -
PLOT DATE = 1/7/2026	DATE - 01/07/2026	REVISED -

STATE OF ILLINOIS
DEPARTMENT OF TRANSPORTATION

BRAINTREE DRIVE
WATER MAIN PLAN AND PROFILE

SCALE: 1"=20' SHEET 5 OF 14 SHEETS STA. 120+00.00 TO STA. 125+00.00

MUN RTE.	SECTION	COUNTY	TOTAL SHEETS	SHEET NO.
4029	23-00146-00-PV	COOK	315	112
CONTRACT NO. 61M26				
ILLINOIS FED. AID PROJECT				

LEGEND

1. PRIOR TO THE START OF WORK, CONTACT NSMJAWA WATCH & PROTECT AT 773.686.0077 AT LEAST 48 HOURS IN ADVANCE FOR INSPECTION. THE UTILITY PAD WILL BE INSTALLED PER THE DETAIL, AND VIBRATION MONITORING, AS REQUESTED, WILL BE IN PLACE PRIOR TO MOVEMENT OF ANY HEAVY MACHINERY NEAR THE DUAL 30" HIGH-PRESSURE PCCP WATERMAINS.

1301 RADCLIFFE LN

FIRE HYDRANTS TO BE REMOVED
8"x6" REDUCER
CONNECTION TO EXISTING
WATER MAIN
VALVE BOXES TO BE REMOVED
REMOVE EXISTING WATER VALVE
WATER MAIN REMOVAL, 6"
(5 LF)

6" ASBESTOS CEMENT
WMAIN _____

7
24
BADCLIFFE LANE

1302 RADCLIFFE LN

44 SEE SHEET 112

45 81' - D I WATER MAIN 12"
TBF = 69 CU YD

46 44' - D I WATER MAIN 8"
TBF = 20 CU YD

47 10' - D I WATER MAIN 8"
TBF = 7 CU YD

48 67' - D I WATER MAIN 12"
TBF = 53 CU YD

49 12' - D I WATER MAIN 8"
TBF = 7 CU YD

50 5' - D I WATER MAIN 6"
TBF = 0 CU YD

51 47' - D I WATER MAIN 12"
TBF = 69 CU YD

52 202' - D I WATER MAIN 12"
TBF = 147 CU YD

1 S BRAINTREE DR

— SEE KINDERMORGAN
NOTES

STEEL CASING PIPE,
AND JACKED, 24"

JACKING/RECEIVING PIT
KINDERMORGAN NOTES:

1. NO MECHANICAL EQUIPMENT IS ALLOWED WITHIN 3 FT OF THE PIPELINE. ALL TRENCHING AROUND THE TOLERANCE ZONE AROUND PIPELINE SHALL BE APPROVED BY THE DAMAGE PREVENTION SUPERVISOR. ANY EXCAVATION WITHIN THE TOLERANCE ZONE SHALL BE BY HYDROVAC, HAND DIGGING, OR OTHER SOFT DIGGING TECHNIQUES. THE CONTRACTOR MUST REPORT OUT TO THE KINDERMORGAN, INC. DAMAGE PREVENTION SUPERVISOR, TO ENSURE A COMPANY REPRESENTATIVE IS ON SITE DURING THE PROJECT.

2. CONTRACTOR MUST HYDRO-EXCAVATE SLIT TRENCH / VIEW PIT, AT AN OFFSET DISTANCE OF 5 FEET FROM SIDE OF PIPE, FOR EACH PIPE CROSSING, FOR KINDERMORGAN DAMAGE PREVENTION INSPECTOR TO ENSURE THE BORE / DIRECTIONAL DRILL DOES NOT HIT THE SIDE OF PIPE AS WELL AS THE DEPTH OF THE BORE / HDD IS BEYOND 24 INCHES BELOW BOTTOM OF PIPE. THE DEPTH OF THE SLIT TRENCH / VIEW PIT MUST AT A DEPTH OF 24 INCHES (MIN), BELOW BOTTOM OF PIPE. THE PURPOSE OF THE PIT IS FOR THE ONSITE INSPECTOR TO ENSURE THE DIRECTIONAL BORE DOES NOT ENTER THE SIDE OF PIPE AND IS NOT WITHIN THE 24 INCH TOLERANCE ZONE. THE BORE / HDD MUST BE AT A DEPTH THAT IT DOES NOT IMPEDE THE VIEW WITHIN THE PIT.



NOTE:

1. MINIMUM COVER OF ALL WATER MAIN PIPES SHALL BE 5.5 FEET.

13 APPX. BOTTOM STORM SEWER = 794.68
TOP PR WATER MAIN = 792.94

15 APPX. BOTTOM WATER MAIN = 791.86
TOP PR WATER MAIN CASING = 783.86

17 APPX. BOTTOM GAS MAIN = 791.85
TOP PR WATER MAIN CASING = 783.86


14 APPX. BOTTOM STORM SEWER = 794.32
TOP PR WATER MAIN = 792.17

16 APPX. BOTTOM WATER MAIN = 791.92'
TOP PR WATER MAIN CASING = 783.86'

18 APPX. BOTTOM GAS MAIN = 791.98
TOP PR WATER MAIN CASING = 783.86

801 S BRAINTREE DR

1 S BRAINTREE DR

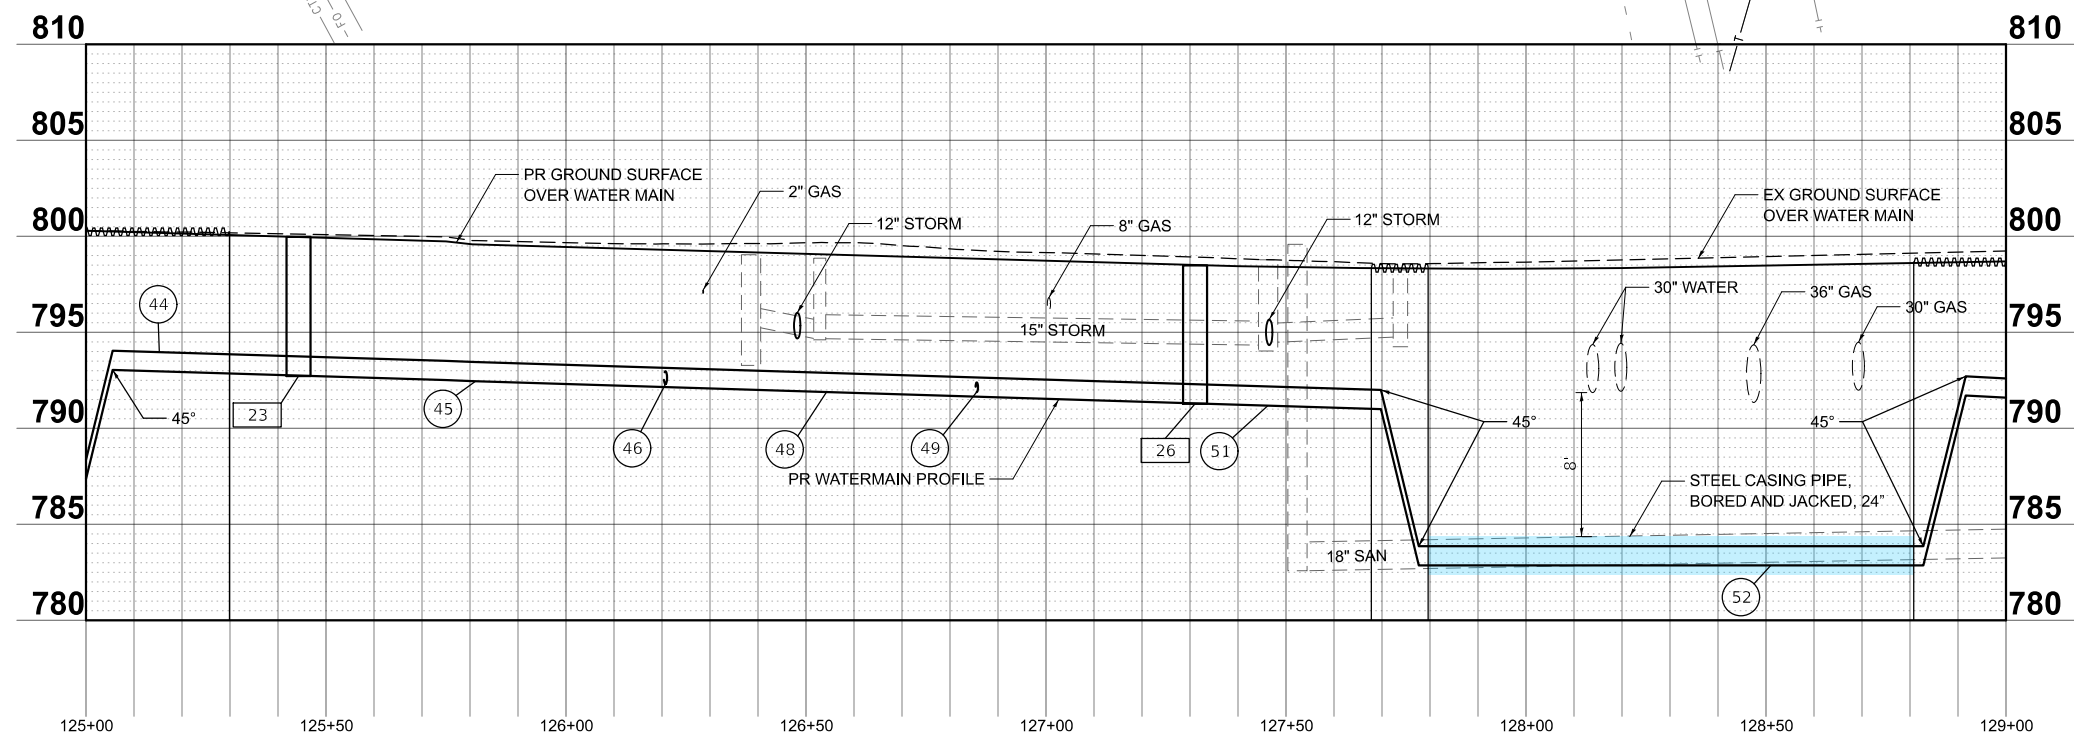

USER NAME = pk	DESIGNED - AMP	REVISED -
	DRAWN - AMP	REVISED -
	CHECKED - PK	REVISED -
PLOT DATE = 1/7/2026	DATE - 01/07/2026	REVISED -

STATE OF ILLINOIS
DEPARTMENT OF TRANSPORTATION

BRAINTREE DRIVE WATER MAIN PLAN AND PROFILE

SCALE: 1"=20'	SHEET 6	OF 14	SHEETS	STA. 125+00.00	TO STA. 129+00.00
---------------	---------	-------	--------	----------------	-------------------

MUN RTE.	SECTION	COUNTY	TOTAL SHEETS	SHEET NO.
4029	23-00146-00-PV	COOK	315	113
		CONTRACT NO. 61M26		
ILLINOIS		FED. AID PROJECT		

MODEL: Braintree - Sheet 6 [Sheet]
FILE NAME: c:\bms\civiltech-pw\petro.kravets\0140565\3993 Watermain.dgn

	WATER MAIN CASING PIPE
	WATER MAIN CASING JACKING SUGGESTED PIT LOCATION
	STEEL CASING PIPE, BORED AND JACKED
	EXISTING VALVE VAULT
	EXISTING VALVE BOX
	PROPOSED VALVE VAULT

1235 CONCORD

29 STA 130+58.0, 29.3' LT
FIRE HYD W/AUX V & VB

30 STA 132+36.7, 57.1' RT
VV TA 5 DIA T1F CL
WATER VALVES 10'
RIM = 800.63

52 SEE SHEET 113

53 69' - D I WATER MAIN 12"
TBF = 73 CU YD



54 43' - D I WATER MAIN 8"
TBF = 28 CU YD

55 5' - D I WATER MAIN 8"
TBF = 0 CU YD

56 59' - D I WATER MAIN 12"
TBF = 49 CU YD

- 57 13' - D I WATER MAIN 8"
TBF = 7 CU YD
- 58 5' - D I WATER MAIN 6"
TBF = 0 CU YD
- 59 199' - D I WATER MAIN 12"
TBF = 161 CU YD
- 60 77' - D I WATER MAIN 10"
TBF = 31 CU YD
- 61 5' - D I WATER MAIN 10"
TBF = 0 CU YD
- 62 183' - D I WATER MAIN 12"
TBF = 154 CU YD

19	APPX. BOTTOM STORM SEWER = 793.74 TOP PR WATER MAIN CASING = 792.24
20	APPX. BOTTOM STORM SEWER = 794.17 TOP PR WATER MAIN = 792.57
21	BOTTOM PR WATER MAIN = 792.99 APPX. TOP SANITARY SEWER = 784.99
22	APPX. BOTTOM STORM SEWER = 795.65 TOP PR WATER MAIN = 793.96
23	BOTTOM PR WATER MAIN = 792.78 APPX. TOP SANITARY SEWER = 786.52

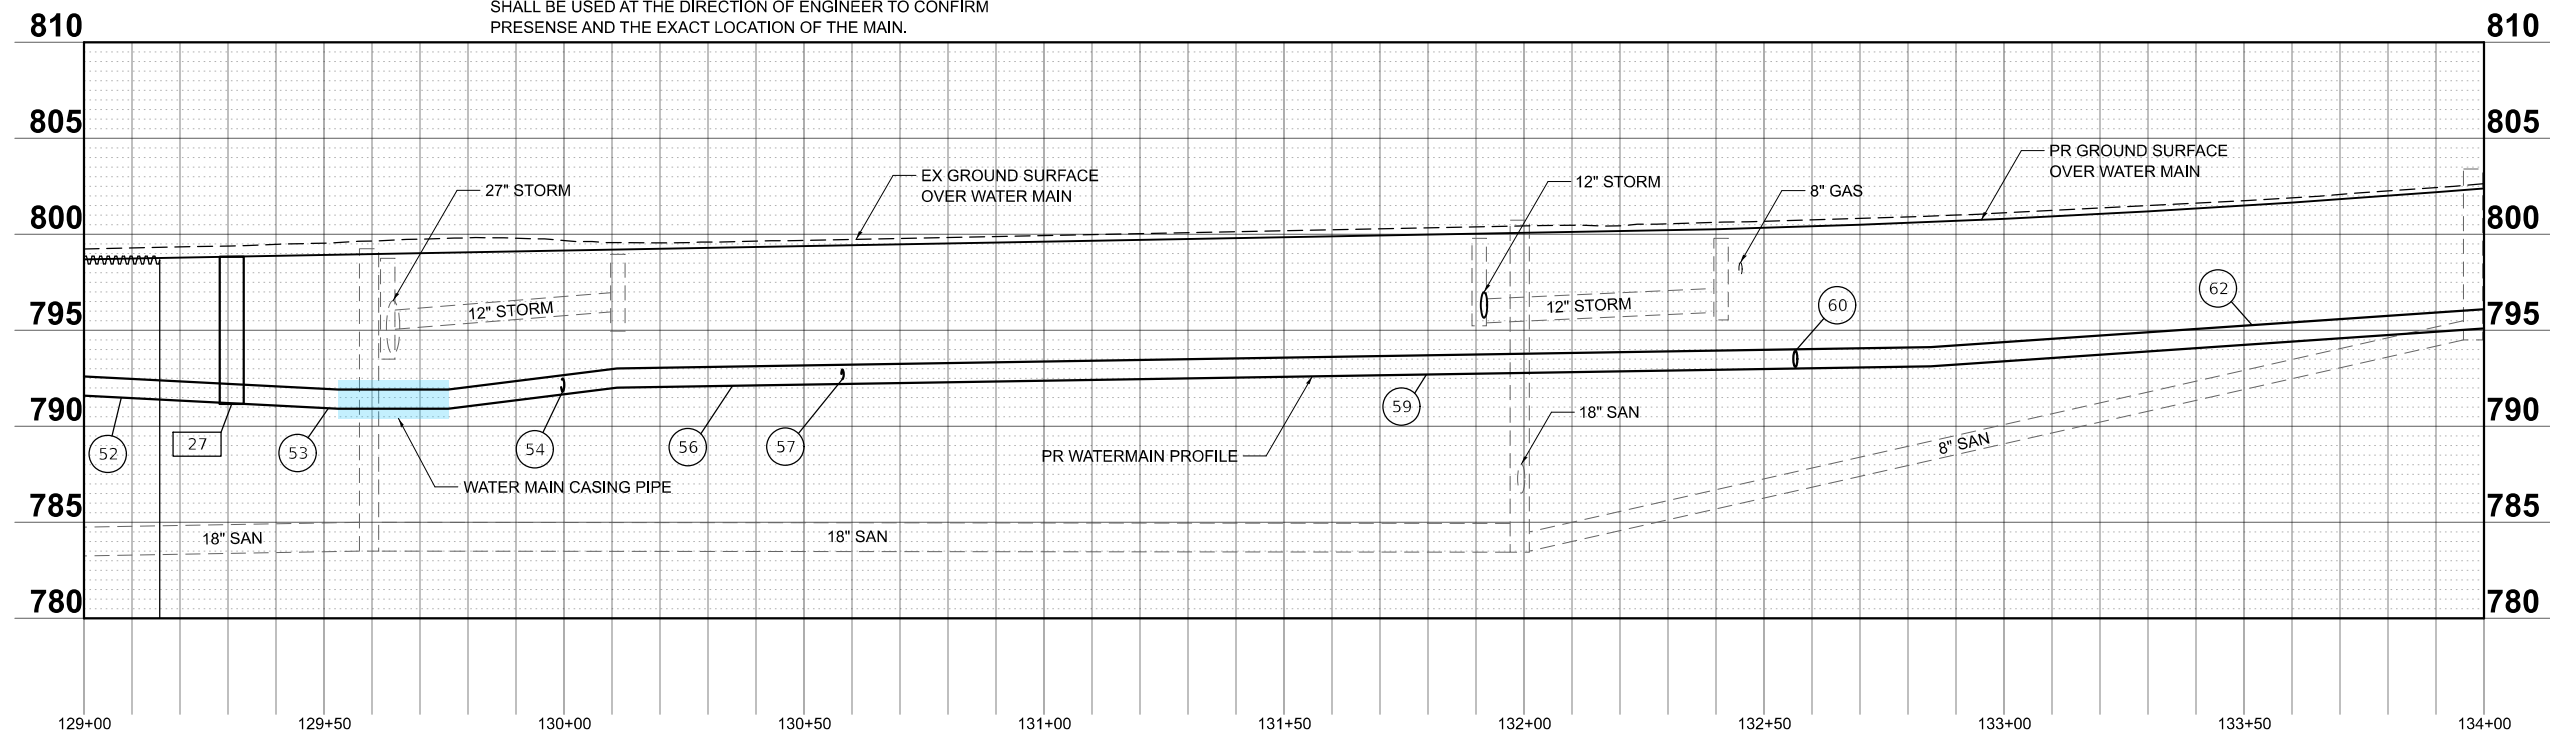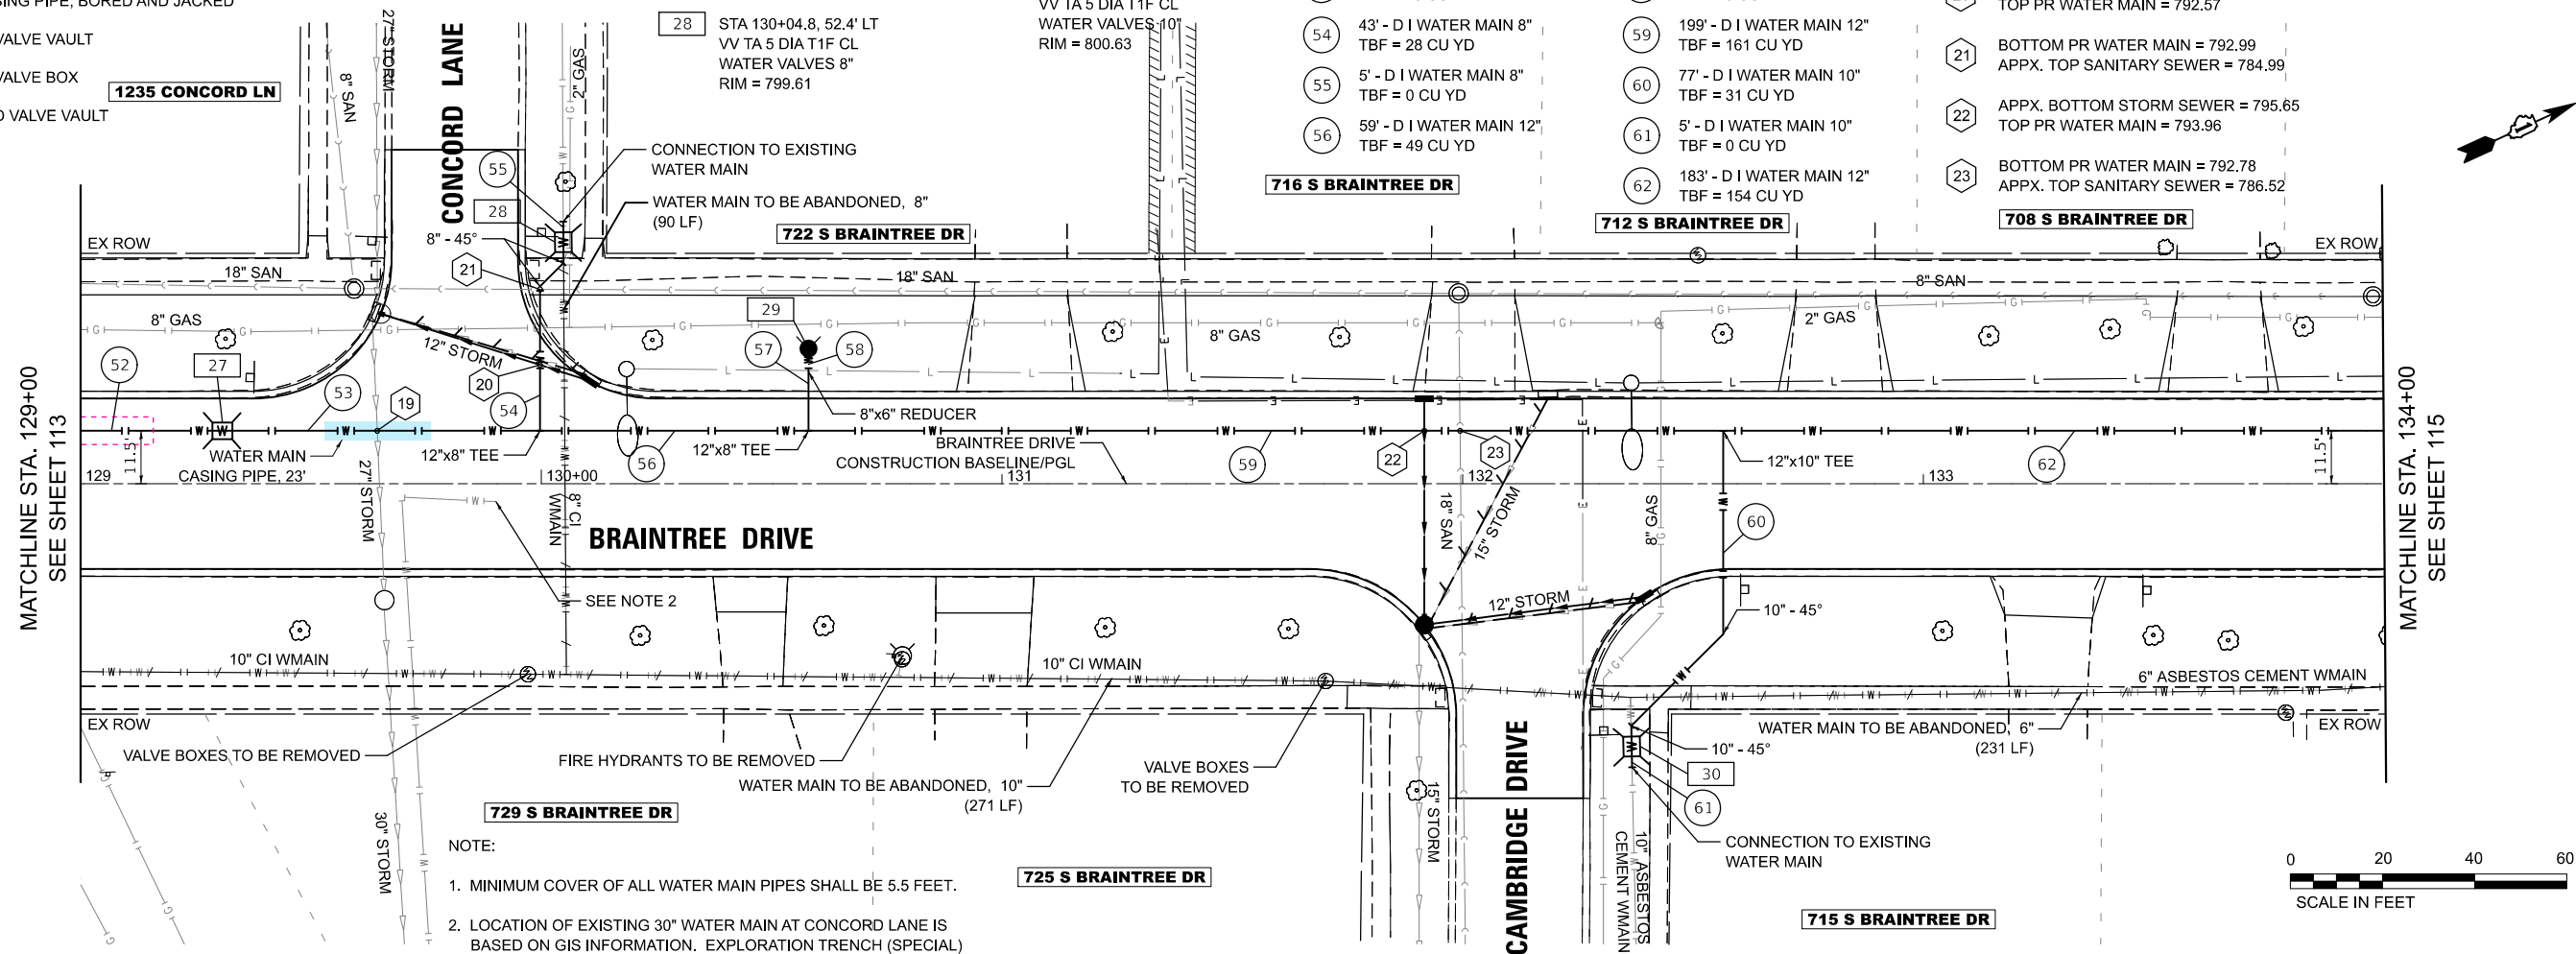

USER NAME = pk	DESIGNED - AMP	REVISED -
	DRAWN - AMP	REVISED -
	CHECKED - PK	REVISED -
PLOT DATE = 1/7/2026	DATE - 01/07/2026	REVISED -

STATE OF ILLINOIS
DEPARTMENT OF TRANSPORTATION

BRAINTREE DRIVE WATER MAIN PLAN AND PROFILE

SCALE: 1"=20'	SHEET 7	OF 14	SHEETS	STA. 129+00.00	TO STA. 134+00.00
---------------	---------	-------	--------	----------------	-------------------

MUN RTE.	SECTION	COUNTY	TOTAL SHEETS	SHEET NO.
4029	23-00146-00-PV	COOK	315	114
		CONTRACT NO. 61M26		
ILLINOIS		FED. AID PROJECT		

MODEL: Braintree - Sheet 7 [Sheet]
FILE NAME: c:\bms\civiltech-pw\petro.kravets\0140565\3993 Watermain.dgn

LEGEND



- WATER MAIN CASING PIPE
- WATER MAIN CASING JACKING
- SUGGESTED PIT LOCATION
- STEEL CASING PIPE, BORED AND JACKED
- EXISTING VALVE VAULT
- EXISTING VALVE BOX
- PROPOSED VALVE VAULT

- 31 STA 134+40.7, 31.4' LT
FIRE HYD W/AUX V & VB
- 32 STA 137+19.8, 31.2' LT
FIRE HYD W/AUX V & VB
- 33 STA 138+00.0, 11.5' LT
VV TA 6 DIA T1F CL
WATER VALVES 12"
RIM = 803.09

- 62 SEE SHEET 114
- 63 15' - D I WATER MAIN 8"
TBF = 7 CU YD
- 64 5' - D I WATER MAIN 6"
TBF = 0 CU YD

- 65 275' - D I WATER MAIN 12"
TBF = 232 CU YD
- 66 15' - D I WATER MAIN 8"
TBF = 7 CU YD
- 67 5' - D I WATER MAIN 6"
TBF = 0 CU YD

- 68 80' - D I WATER MAIN 12"
TBF = 65 CU YD
- 69 225' - D I WATER MAIN 12"
TBF = 169 CU YD

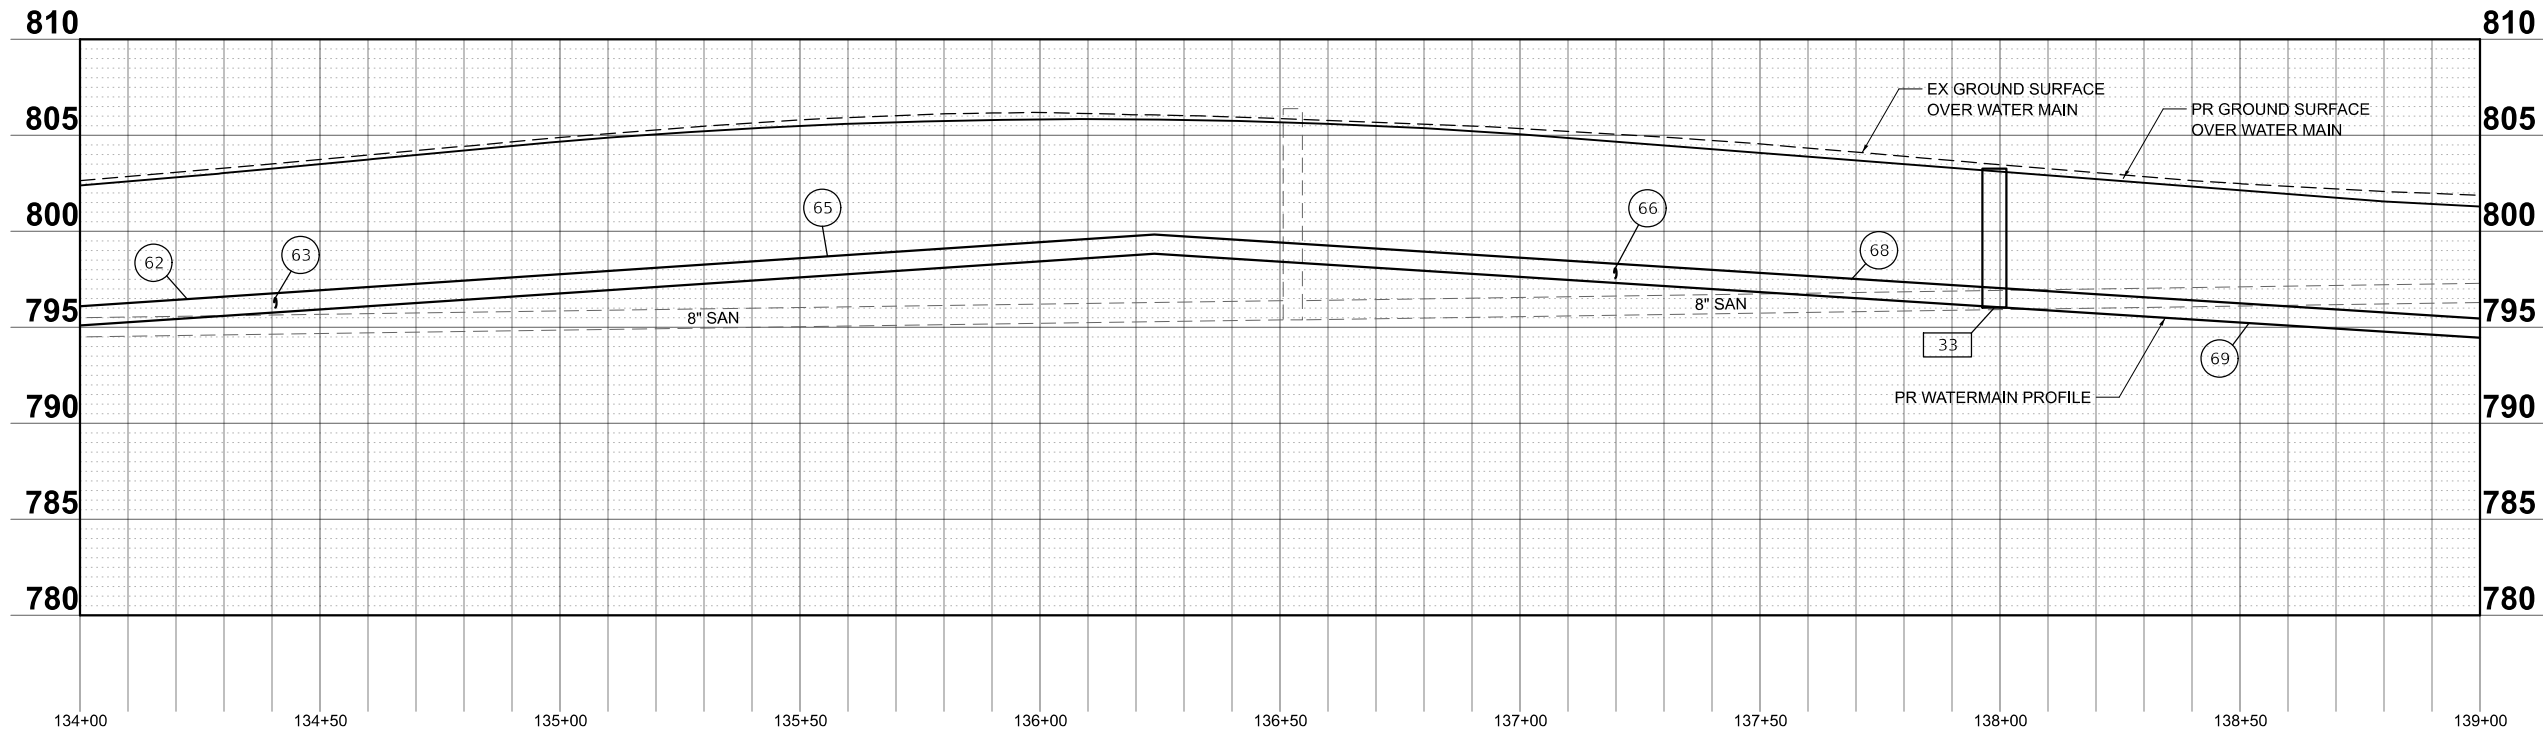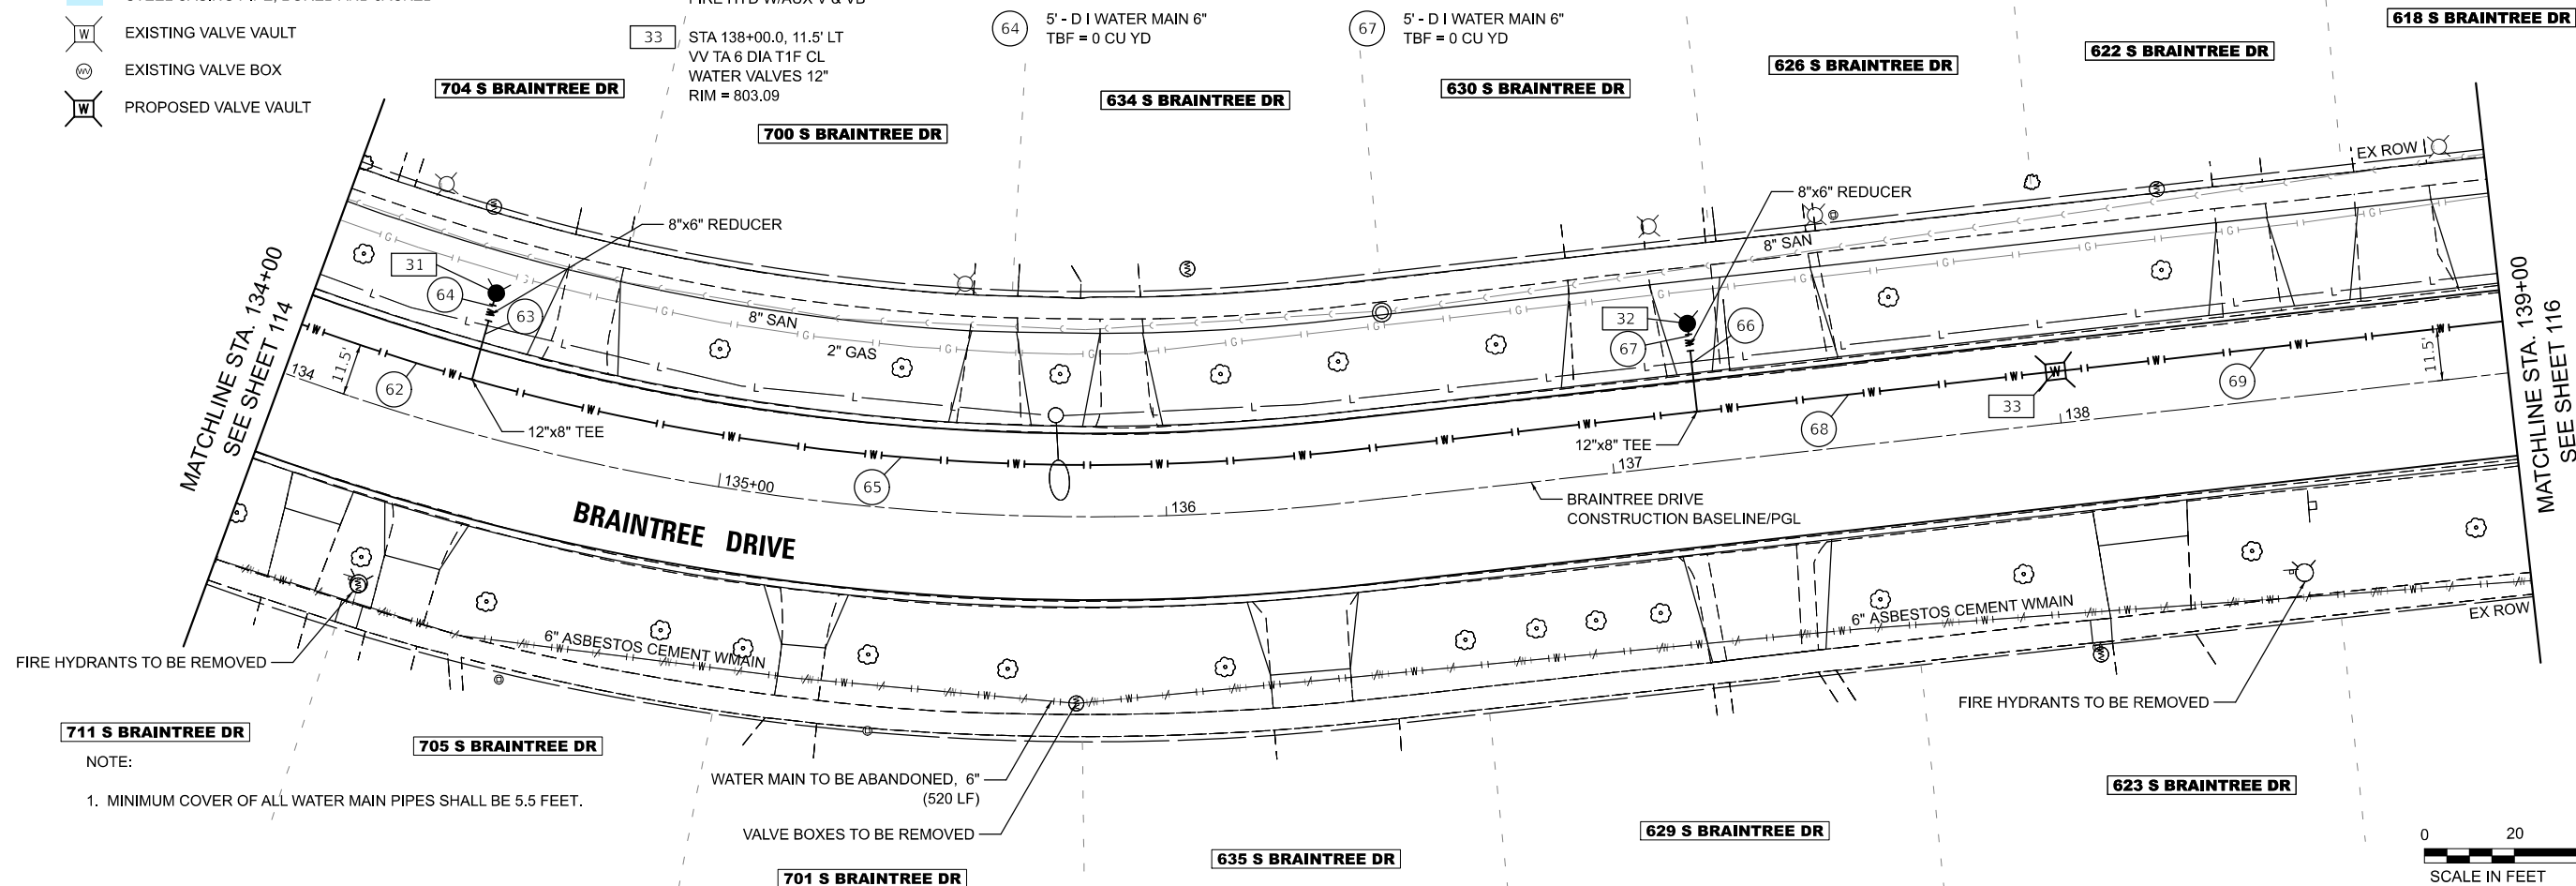

MODEL: Braintree - Sheet 8 [Sheet]
FILE NAME: c:\bms\sch\tech-pw\pairo_kravets\0140565\3983_Watermain.dgn

USER NAME = pk	DESIGNED - AMP	REVISED -
	DRAWN - AMP	REVISED -
	CHECKED - PK	REVISED -
PLOT DATE = 1/7/2026	DATE - 01/07/2026	REVISED -

STATE OF ILLINOIS
DEPARTMENT OF TRANSPORTATION

BRAINTREE DRIVE
WATER MAIN PLAN AND PROFILE

SCALE: 1"=20' SHEET 8 OF 14 SHEETS STA. 134+00.00 TO STA. 139+00.00

MUN RTE.	SECTION	COUNTY	TOTAL SHEETS	SHEET NO.
4029	23-00146-00-PV	COOK	315	115
CONTRACT NO. 61M26				
ILLINOIS FED. AID PROJECT				


LEGEND

- WATER MAIN CASING PIPE
WATER MAIN CASING JACKING
SUGGESTED PIT LOCATION
STEEL CASING PIPE, BORED AND JACKED
EXISTING VALVE VAULT
EXISTING VALVE BOX
PROPOSED VALVE VAULT

- 34 STA 140+27.7, 31.4' LT
FIRE HYD W/AUX V & VB
35 STA 142+76.5, 28.7' LT
FIRE HYD W/AUX V & VB
36 STA 143+23.9, 48.7' LT
VV TA 5 DIA T1F CL
WATER VALVES 8"
RIM = 802.32

- 69 SEE SHEET 115
70 15' - D I WATER MAIN 8"
TBF = 7 CU YD
71 5' - D I WATER MAIN 6"
TBF = 0 CU YD
72 258' - D I WATER MAIN 12"
TBF = 203 CU YD
73 5' - D I WATER MAIN 6"
TBF = 0 CU YD


- 74 65' - D I WATER MAIN 12"
TBF = 51 CU YD
75 17' - D I WATER MAIN 8"
TBF = 10 CU YD
76 5' - D I WATER MAIN 8"
TBF = 0 CU YD
77 186' - D I WATER MAIN 12"
TBF = 181 CU YD

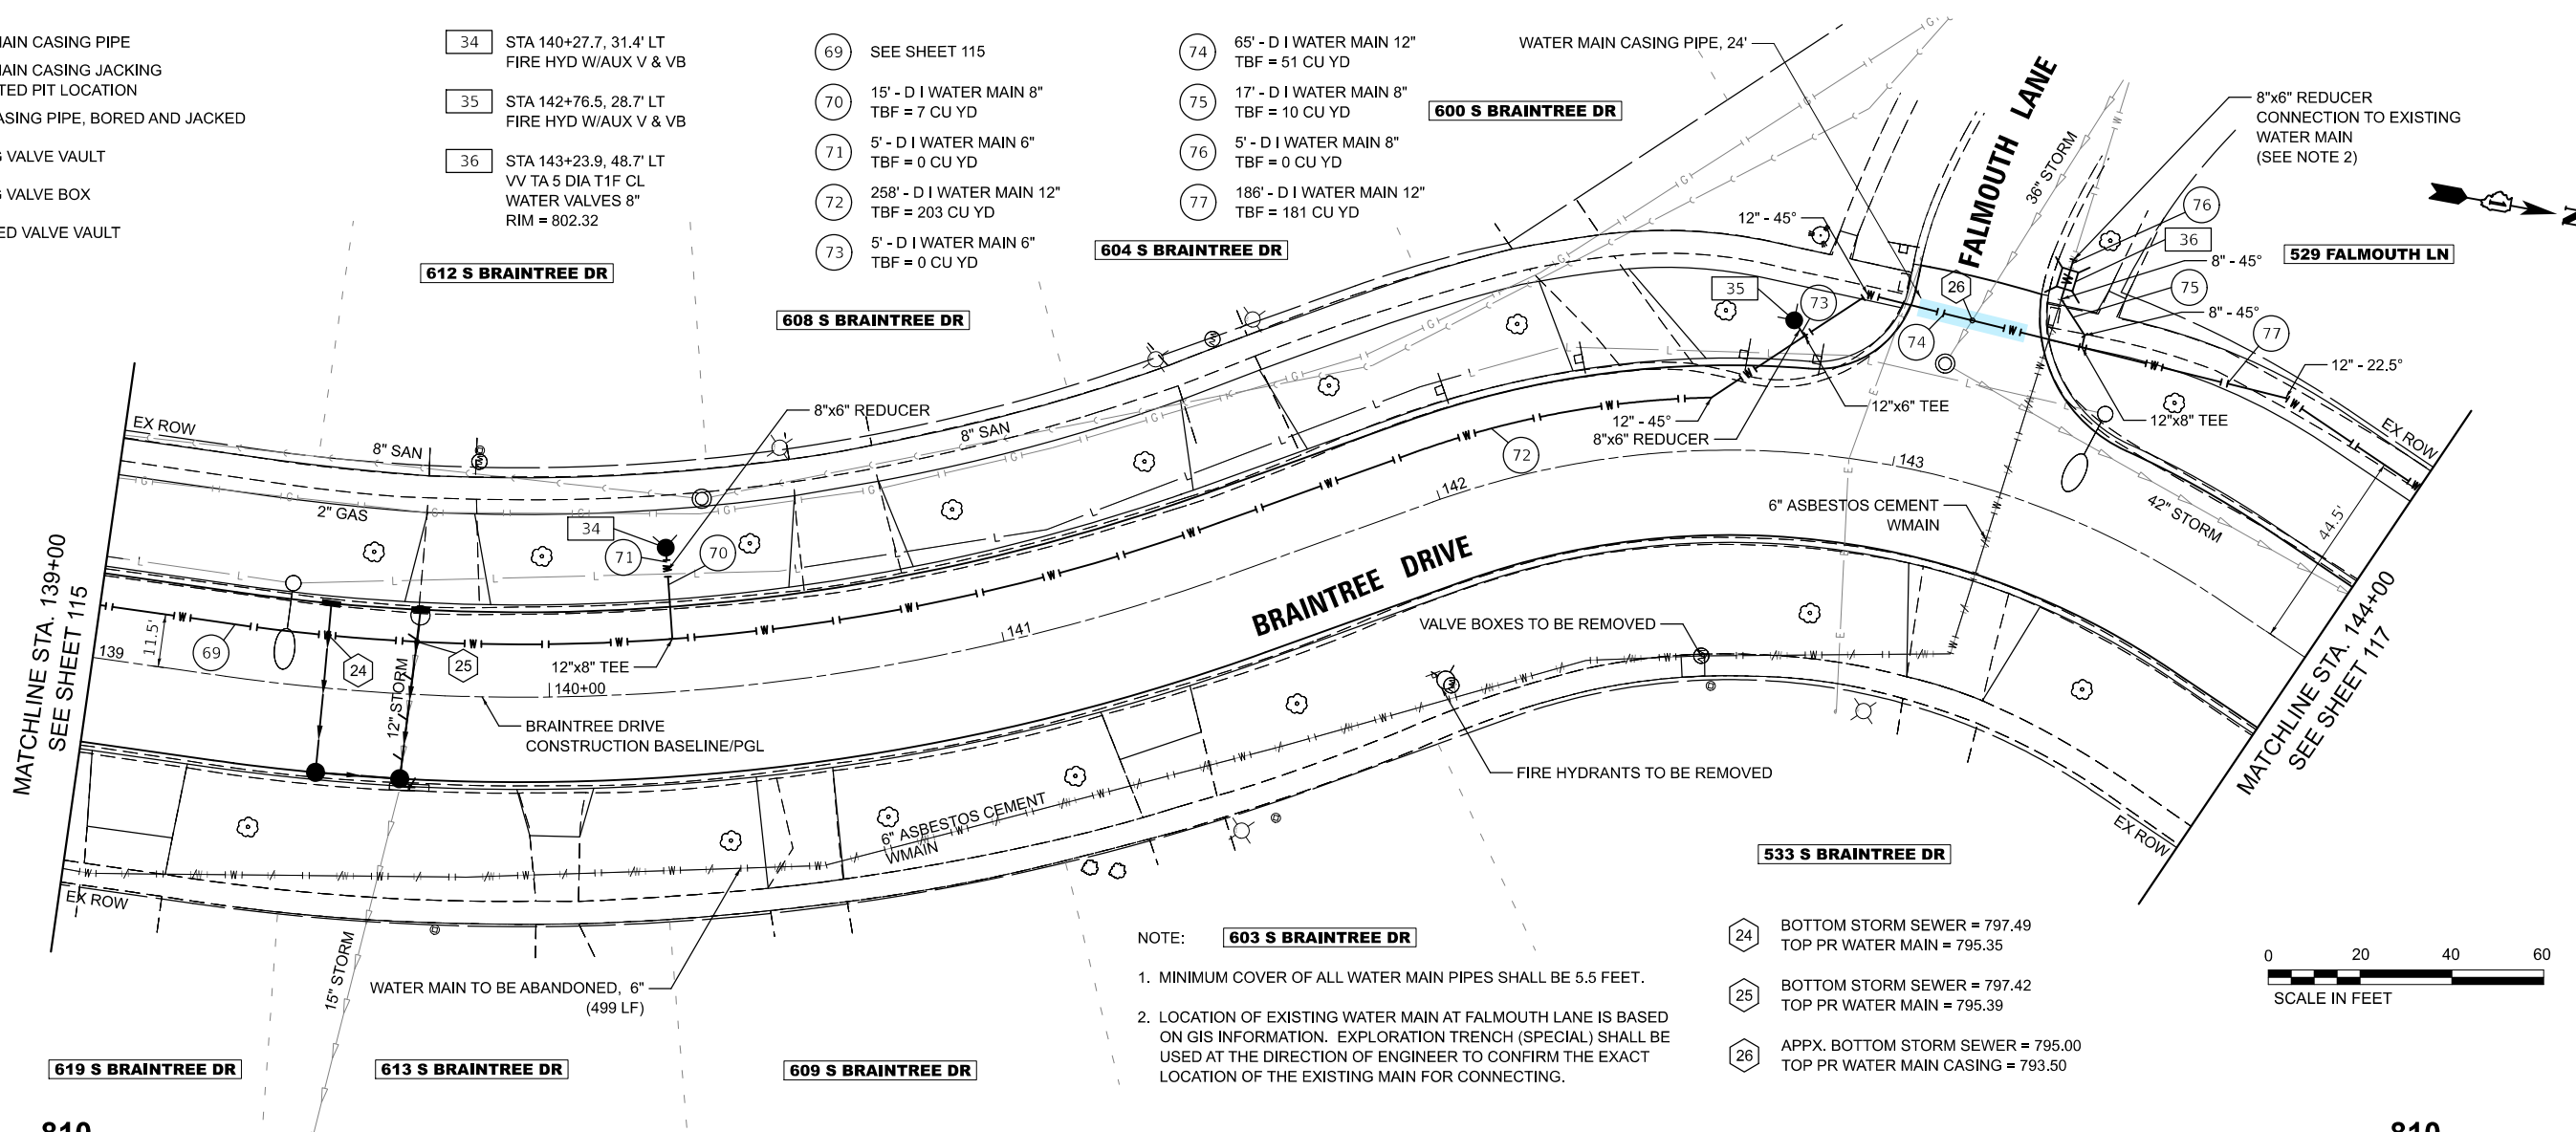

NOTE:

- 603 S BRAINTREE DR
1. MINIMUM COVER OF ALL WATER MAIN PIPES SHALL BE 5.5 FEET.
2. LOCATION OF EXISTING WATER MAIN AT FALMOUTH LANE IS BASED ON GIS INFORMATION. EXPLORATION TRENCH (SPECIAL) SHALL BE USED AT THE DIRECTION OF ENGINEER TO CONFIRM THE EXACT LOCATION OF THE EXISTING MAIN FOR CONNECTING.

- 24 BOTTOM STORM SEWER = 797.49
TOP PR WATER MAIN = 795.35
25 BOTTOM STORM SEWER = 797.42
TOP PR WATER MAIN = 795.39
26 APPX. BOTTOM STORM SEWER = 795.00
TOP PR WATER MAIN CASING = 793.50

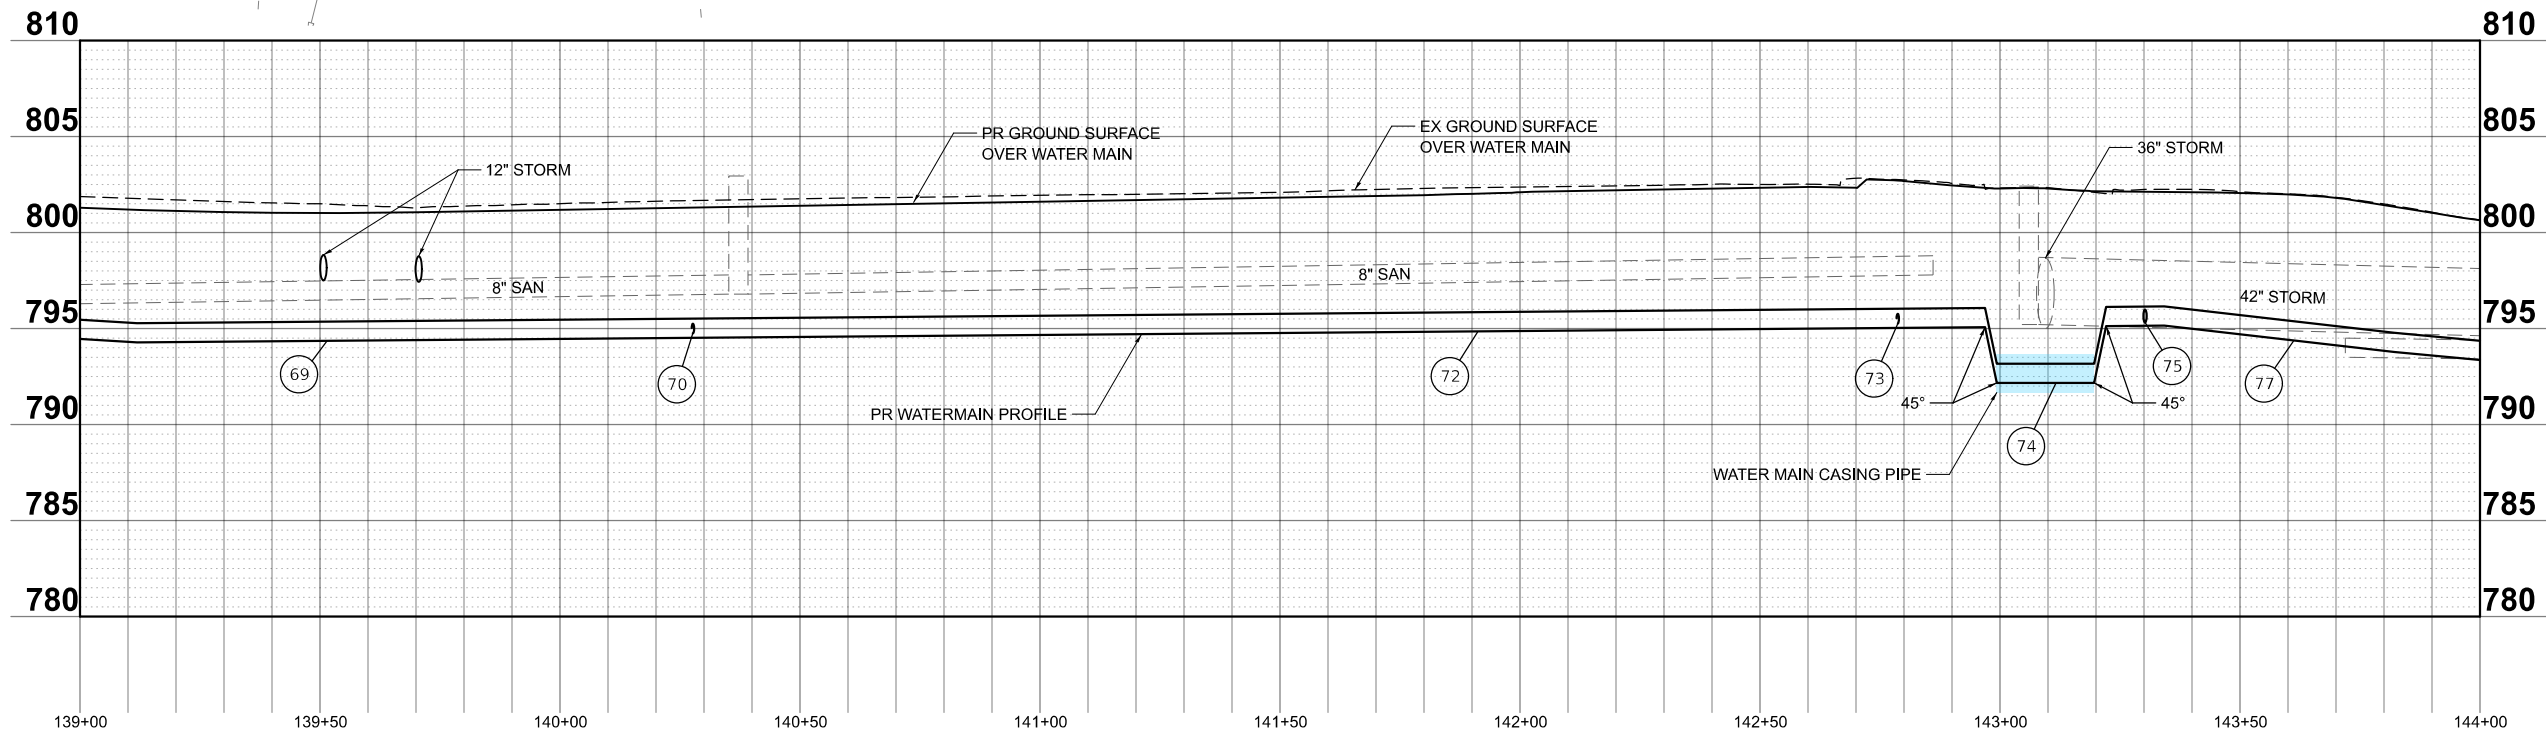

USER NAME = pk	DESIGNED - AMP	REVISED -
	DRAWN - AMP	REVISED -
	CHECKED - PK	REVISED -
PLOT DATE = 1/7/2026	DATE - 01/07/2026	REVISED -

STATE OF ILLINOIS
DEPARTMENT OF TRANSPORTATION

BRAINTREE DRIVE
WATER MAIN PLAN AND PROFILE

SCALE: 1"=20' SHEET 9 OF 14 SHEETS STA. 139+00.00 TO STA. 144+00.00

MUN RTE.	SECTION	COUNTY	TOTAL SHEETS	SHEET NO.
4029	23-00146-00-PV	COOK	315	116
CONTRACT NO. 61M26				
ILLINOIS FED. AID PROJECT				


LEGEND

- WATER MAIN CASING PIPE
- WATER MAIN CASING JACKING
SUGGESTED PIT LOCATION
- STEEL CASING PIPE, BORED AND JACKED
- EXISTING VALVE VAULT
- EXISTING VALVE BOX
- PROPOSED VALVE VAULT


- 37 STA 145+05.0, 44.5' LT
VV TA 6 DIA T1F CL
WATER VALVES 12"
RIM = 798.16
- 38 STA 146+53.0, 36.0' LT
FIRE HYD W/AUX V & VB
- 39 STA 147+31.3, 37.6' LT
VV TA 5 DIA T1F CL
WATER VALVES 10"
RIM = 806.31

- 77 SEE SHEET 116
- 78 148' - D I WATER MAIN 12"
TBF = 158 CU YD
- 79 4' - D I WATER MAIN 8"
TBF = 7 CU YD
- 80 5' - D I WATER MAIN 6"
TBF = 0 CU YD

- 81 74' - D I WATER MAIN 12"
TBF = 85 CU YD
- 82 7' - D I WATER MAIN 10"
TBF = 6 CU YD
- 83 129' - D I WATER MAIN 10"
TBF = 80 CU YD
- 84 232' - D I WATER MAIN 12"
TBF = 256 CU YD

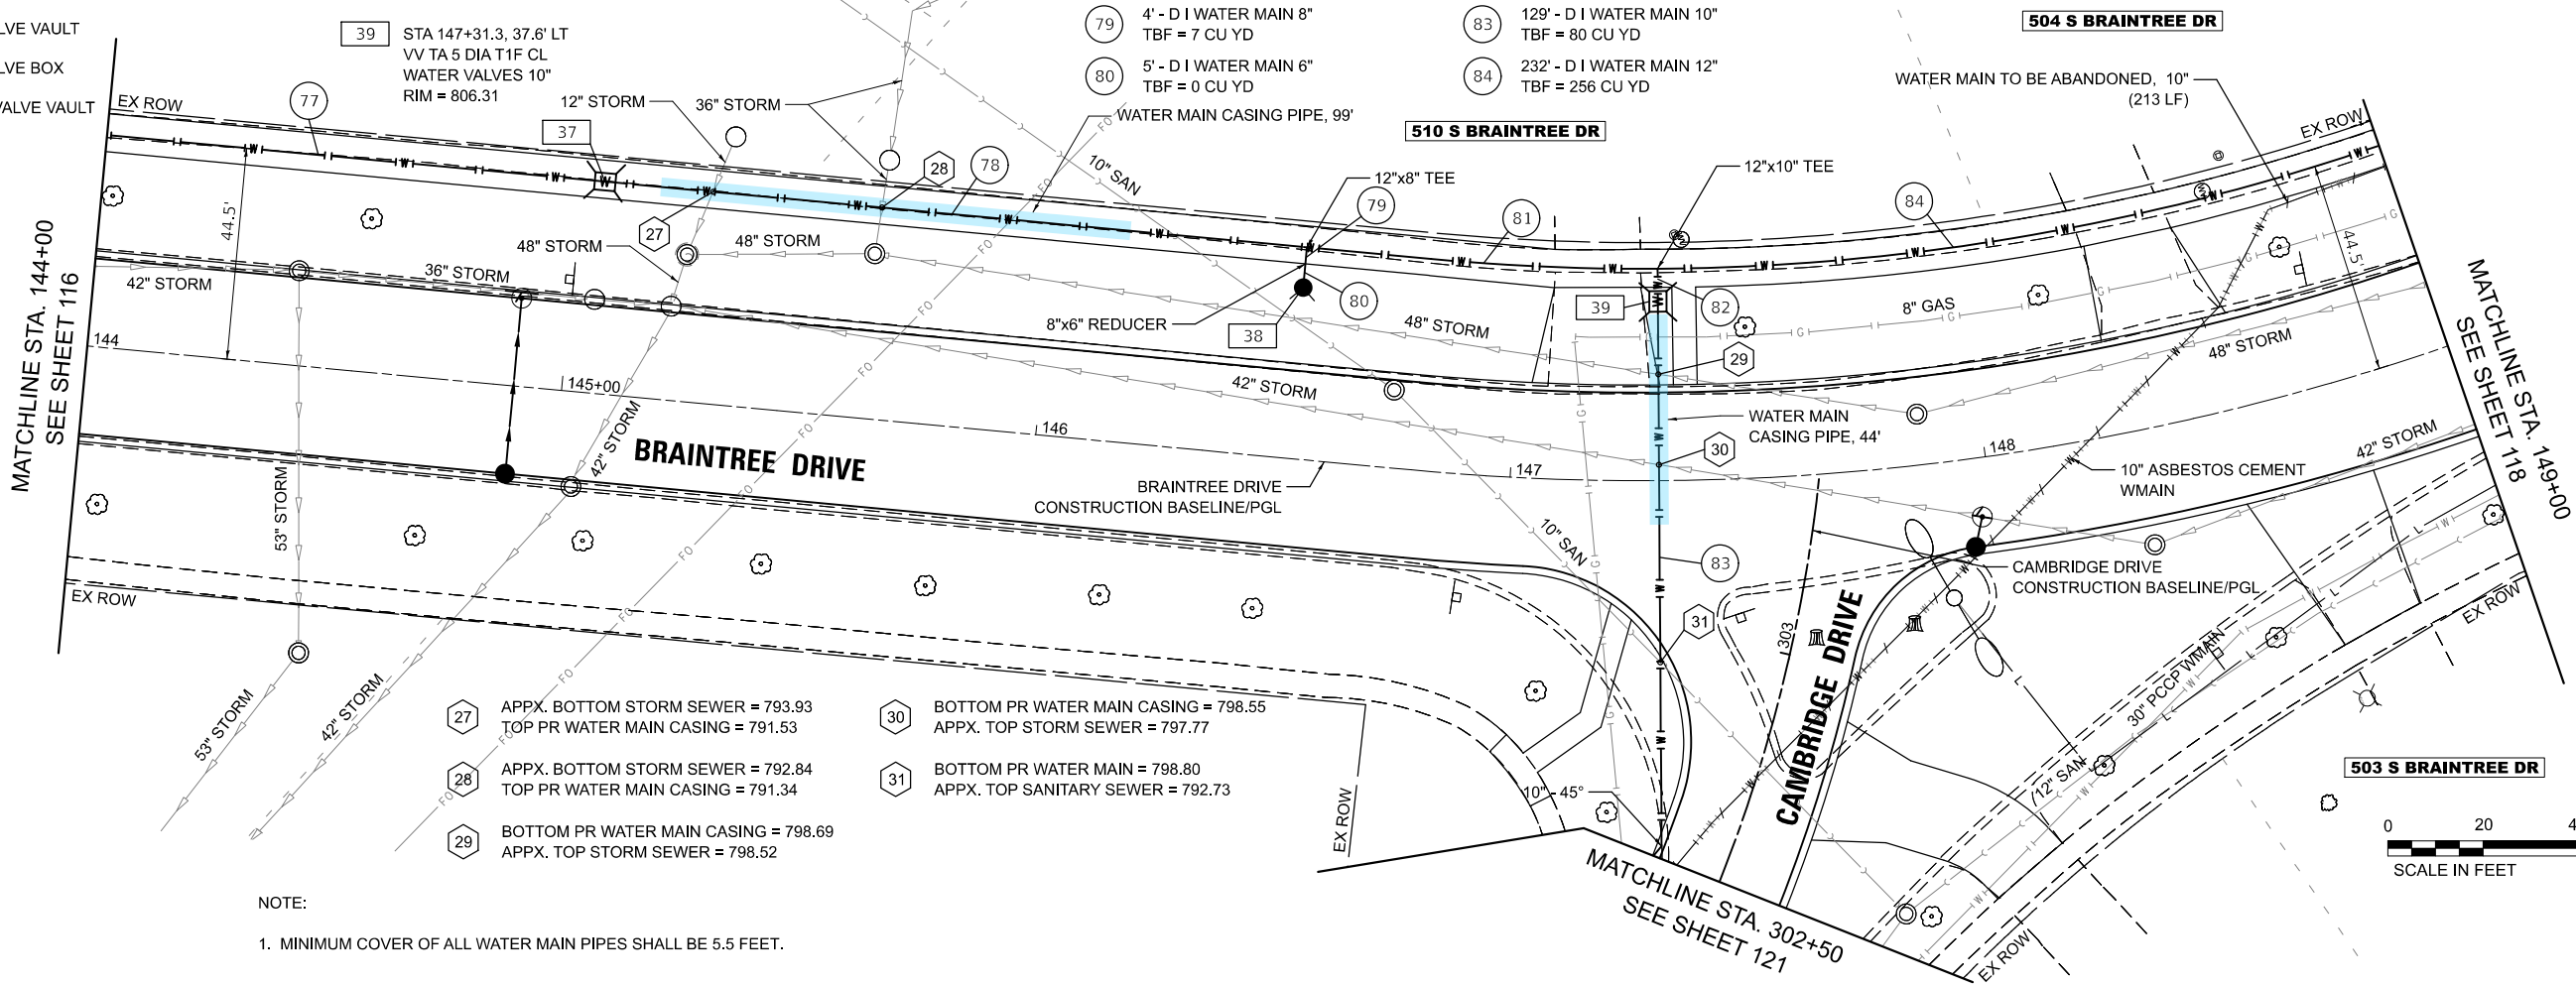

NOTE:
1. MINIMUM COVER OF ALL WATER MAIN PIPES SHALL BE 5.5 FEET.

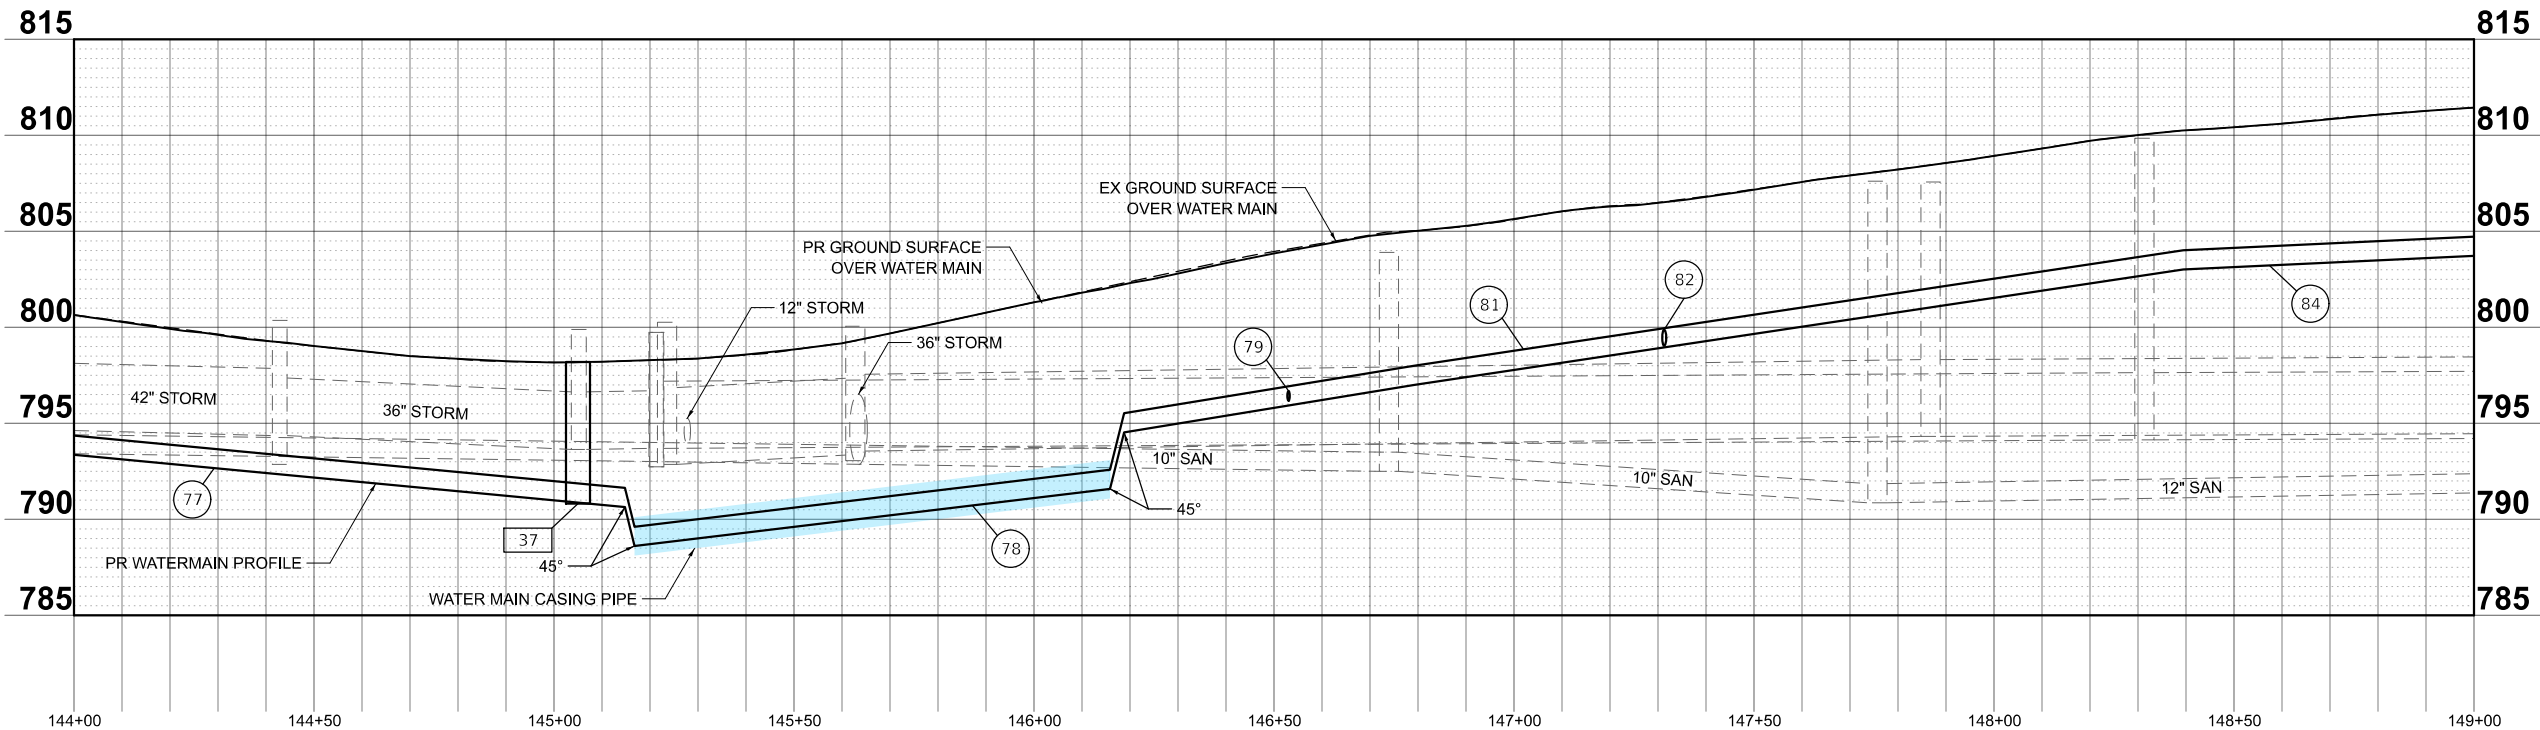

USER NAME = pk	DESIGNED - AMP	REVISED -
	DRAWN - AMP	REVISED -
	CHECKED - PK	REVISED -
PLOT DATE = 1/7/2026	DATE - 01/07/2026	REVISED -

STATE OF ILLINOIS
DEPARTMENT OF TRANSPORTATION

BRAINTREE DRIVE
WATER MAIN PLAN AND PROFILE

SCALE: 1"=20' SHEET 10 OF 14 SHEETS STA. 144+00.00 TO STA. 149+00.00


MUN RTE.	SECTION	COUNTY	TOTAL SHEETS	SHEET NO.
4029	23-00146-00-PV	COOK	315	117
CONTRACT NO. 61M26				
ILLINOIS FED. AID PROJECT				

LEGEND

- WATER MAIN CASING PIPE
- WATER MAIN CASING JACKING
- SUGGESTED PIT LOCATION
- STEEL CASING PIPE, BORED AND JACKED
- EXISTING VALVE VAULT
- EXISTING VALVE BOX
- PROPOSED VALVE VAULT


- 40 STA 149+77.0, 35.1' LT FIRE HYD W/AUX V & VB
- 41 STA 152+19.7, 63.5' LT VV TA 5 DIA T1F CL WATER VALVES 8" RIM = 807.20
- 42 STA 152+64.1, 22.2' LT VV TA 6 DIA T1F CL WATER VALVES 30" RIM = 806.11
- 43 STA 152+45.7, 44.5' LT VV TA 6 DIA T1F CL WATER VALVES 12" RIM = 806.87
- 44 STA 153+23.1, 29.3' LT FIRE HYD W/AUX V & VB
- 45 STA 153+75.24, 22.2' LT VV TA 6 DIA T1F CL WATER VALVES 12" RIM = 803.21

- 84 SEE SHEET 117
- 85 4' - D I WATER MAIN 8" TBF = 7 CU YD
- 86 5' - D I WATER MAIN 6" TBF = 0 CU YD
- 87 261' - D I WATER MAIN 12" TBF = 253 CU YD
- 88 24' - D I WATER MAIN 8" TBF = 7 CU YD
- 89 5' - D I WATER MAIN 8" TBF = 0 CU YD
- 90 18' - D I WATER MAIN 12" TBF = 19 CU YD

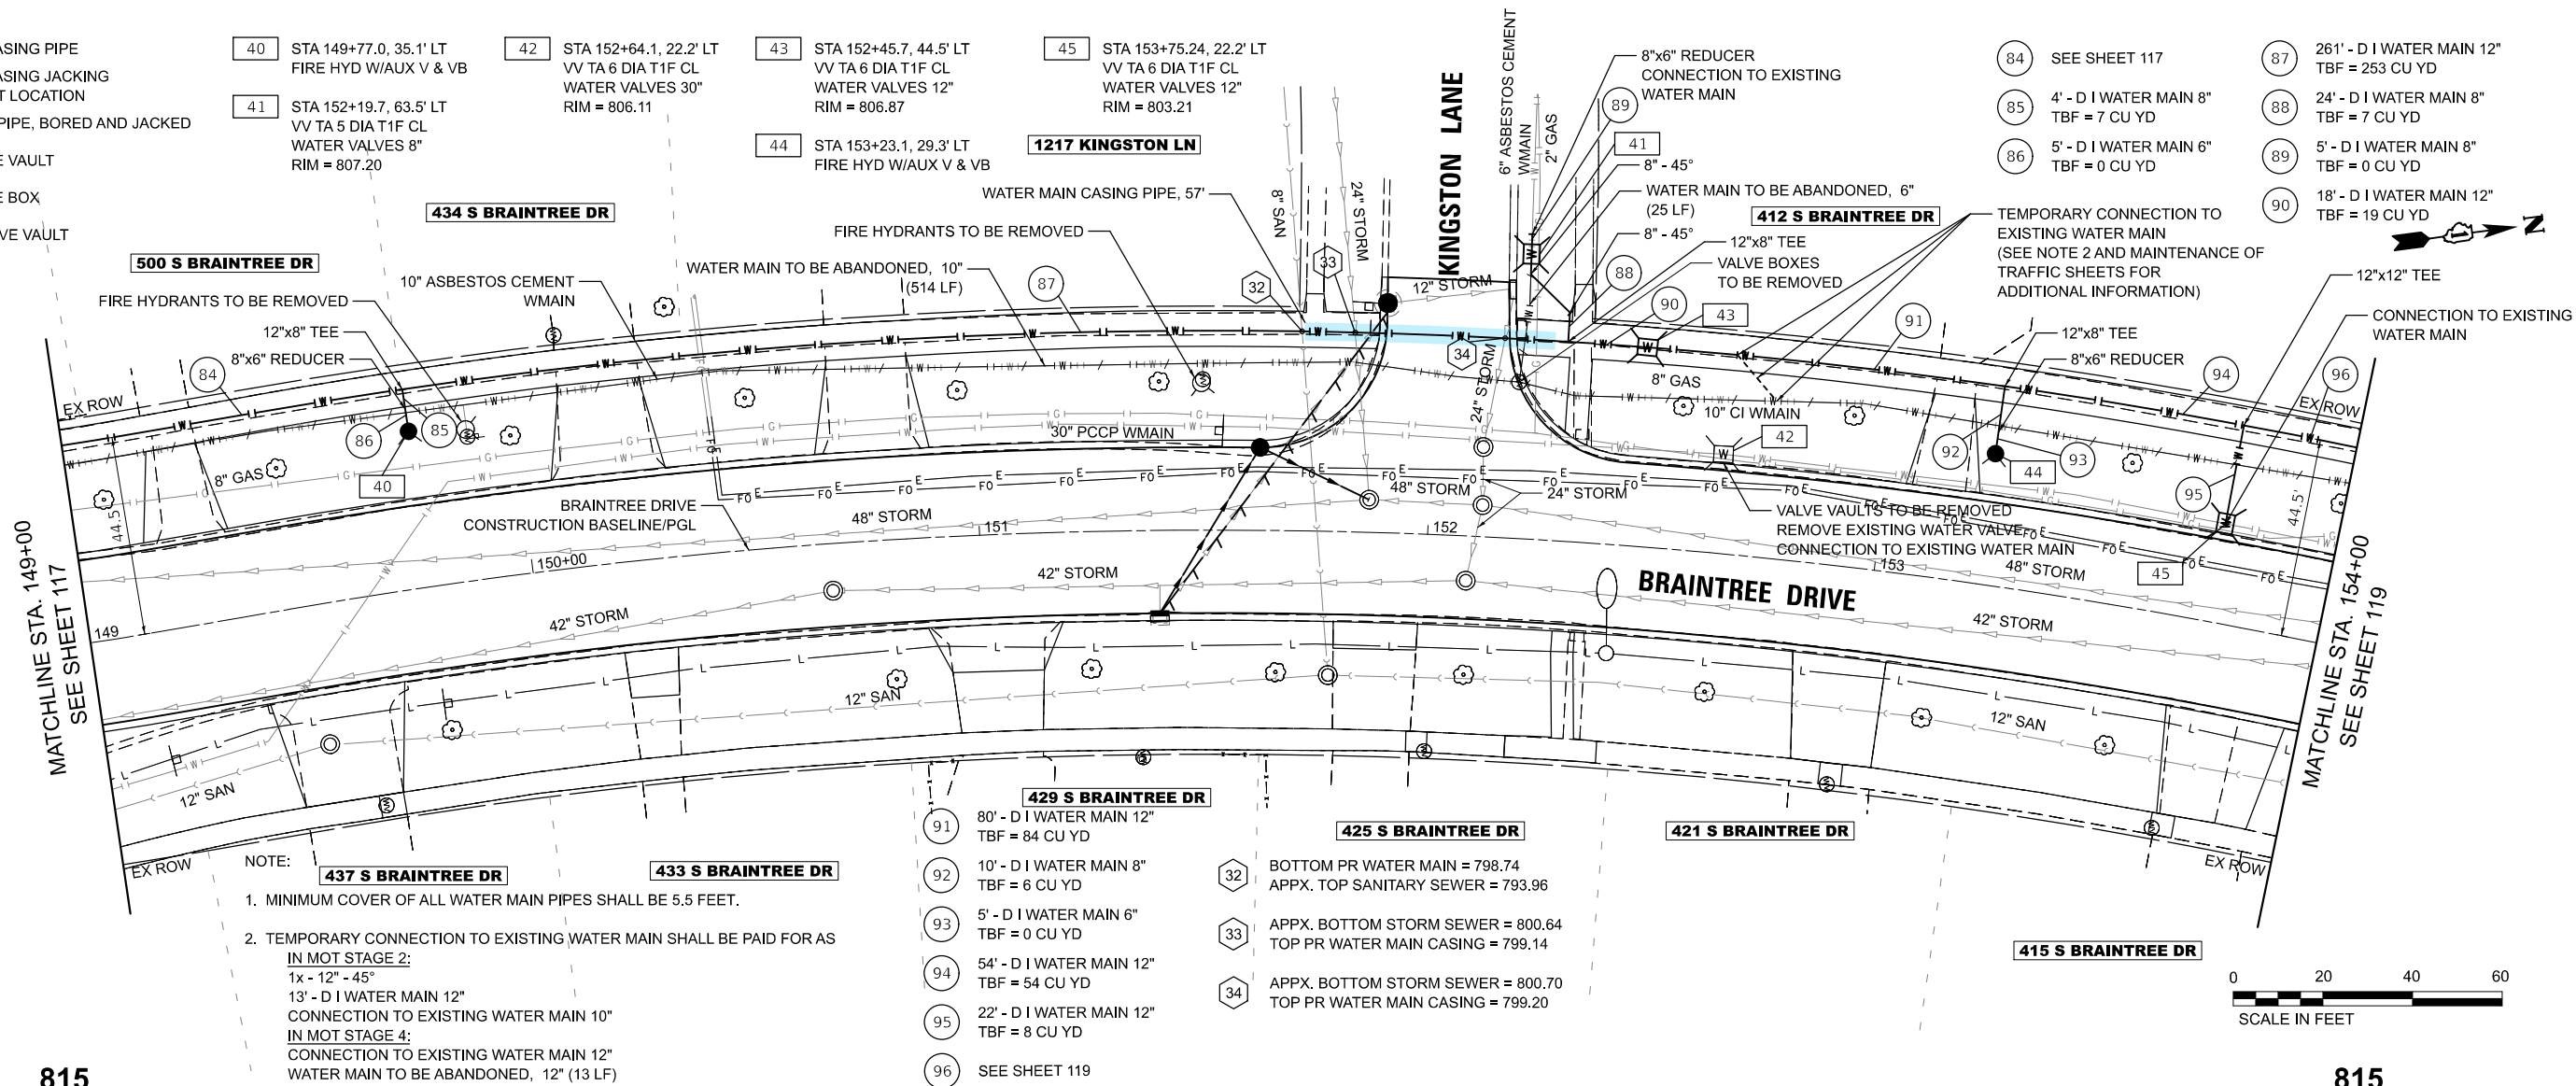

NOTE:
1. MINIMUM COVER OF ALL WATER MAIN PIPES SHALL BE 5.5 FEET.
2. TEMPORARY CONNECTION TO EXISTING WATER MAIN SHALL BE PAID FOR AS
IN MOT STAGE 2:
1x - 12" - 45°
13' - D I WATER MAIN 12"
CONNECTION TO EXISTING WATER MAIN 10"
IN MOT STAGE 4:
CONNECTION TO EXISTING WATER MAIN 12"
WATER MAIN TO BE ABANDONED, 12" (13 LF)

- 429 S BRAINTREE DR
80' - D I WATER MAIN 12" TBF = 84 CU YD
- 425 S BRAINTREE DR
10' - D I WATER MAIN 8" TBF = 6 CU YD
- 421 S BRAINTREE DR
5' - D I WATER MAIN 6" TBF = 0 CU YD
- 415 S BRAINTREE DR
54' - D I WATER MAIN 12" TBF = 54 CU YD
- 22' - D I WATER MAIN 12" TBF = 8 CU YD
- SEE SHEET 119

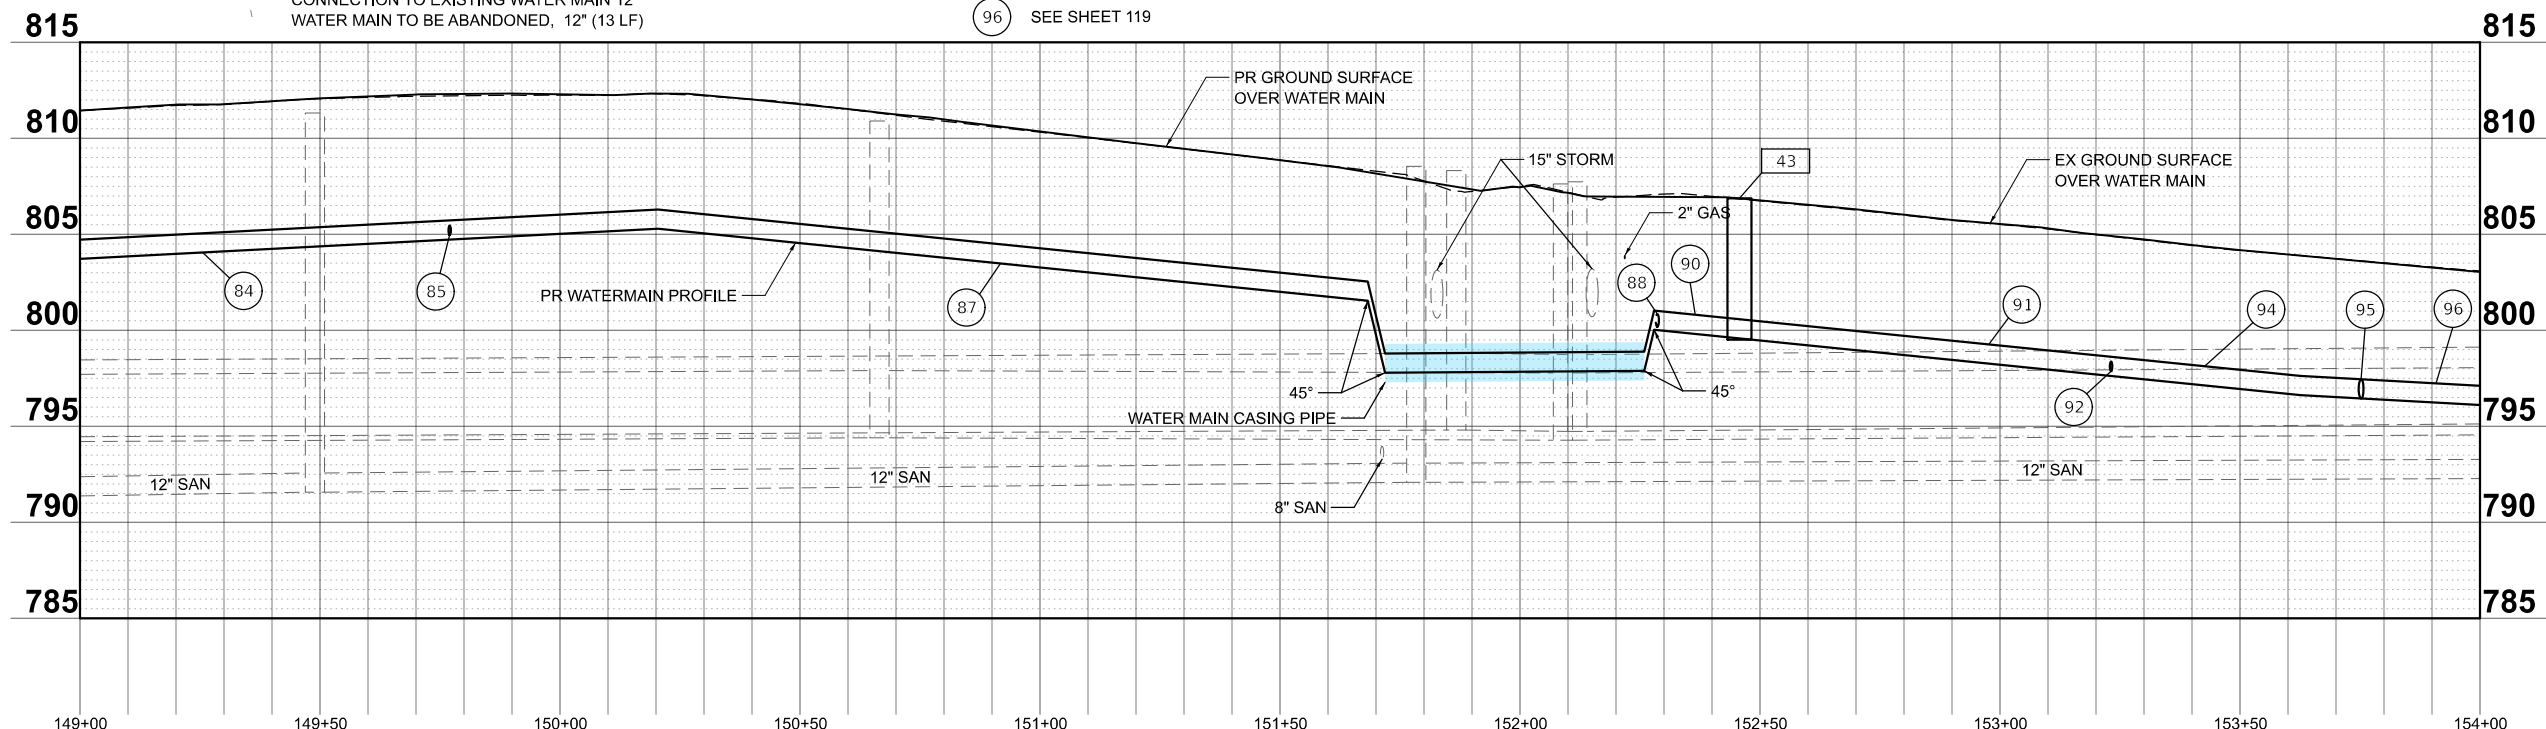

USER NAME = pk	DESIGNED - AMP	REVISED -
	DRAWN - AMP	REVISED -
	CHECKED - PK	REVISED -
PLOT DATE = 1/7/2026	DATE - 01/07/2026	REVISED -

STATE OF ILLINOIS
DEPARTMENT OF TRANSPORTATION

BRAINTREE DRIVE
WATER MAIN PLAN AND PROFILE

SCALE: 1"=20' SHEET 11 OF 14 SHEETS STA. 149+00.00 TO STA. 154+00.00

MUN RTE.	SECTION	COUNTY	TOTAL SHEETS	SHEET NO.
4029	23-00146-00-PV	COOK	315	118
CONTRACT NO. 61M26				
ILLINOIS FED. AID PROJECT				

MODEL: Braintree - Sheet 11 [Sheet]
FILE NAME: c:\bms\chiltech-pv\pairo.kravets\014056513993.Watermain.dgn

LEGEND

- WATER MAIN CASING PIPE
WATER MAIN CASING JACKING
SUGGESTED PIT LOCATION
STEEL CASING PIPE, BORED AND JACKED
EXISTING VALVE VAULT
EXISTING VALVE BOX
PROPOSED VALVE VAULT


- 46 STA 156+81.1, 75.4' LT
VV TA 6 DIA T1F CL
WATER VALVES 12"
RIM = 801.75
47 STA 156+08.5, 86.1' RT
FIRE HYD W/AUX V & VB
48 STA 156+04.8, 102.5' RT
VV TA 6 DIA T1F CL
WATER VALVES 12"
RIM = 800.94

- 49 STA 157+06.8, 23.9' LT
VV TA 6 DIA T1F CL
WATER VALVES 30"
RIM = 801.23
50 STA 157+00.0, 29.1' LT
FIRE HYD W/AUX V & VB
51 STA 157+70.0, 13.0' LT
VV TA 6 DIA T1F CL
WATER VALVES 12"
RIM = 801.26

- 96 316' - D I WATER MAIN 12"
TBF = 232 CU YD
97 64' - D I WATER MAIN 12"
TBF = 46 CU YD
98 5' - D I WATER MAIN 12"
TBF = 5 CU YD

- 99 139' - D I WATER MAIN 12"
TBF = 72 CU YD
100 3' - D I WATER MAIN 8"
TBF = 0 CU YD
101 5' - D I WATER MAIN 6"
TBF = 0 CU YD
102 14' - D I WATER MAIN 12"
TBF = 0 CU YD
103 5' - D I WATER MAIN 12"
TBF = 0 CU YD
104 22' - D I WATER MAIN 12"
TBF = 18 CU YD

- 105 11' - D I WATER MAIN 8"
TBF = 7 CU YD
106 5' - D I WATER MAIN 6"
TBF = 0 CU YD
107 68' - D I WATER MAIN 12"
TBF = 50 CU YD
108 12' - D I WATER MAIN 12"
TBF = 10 CU YD

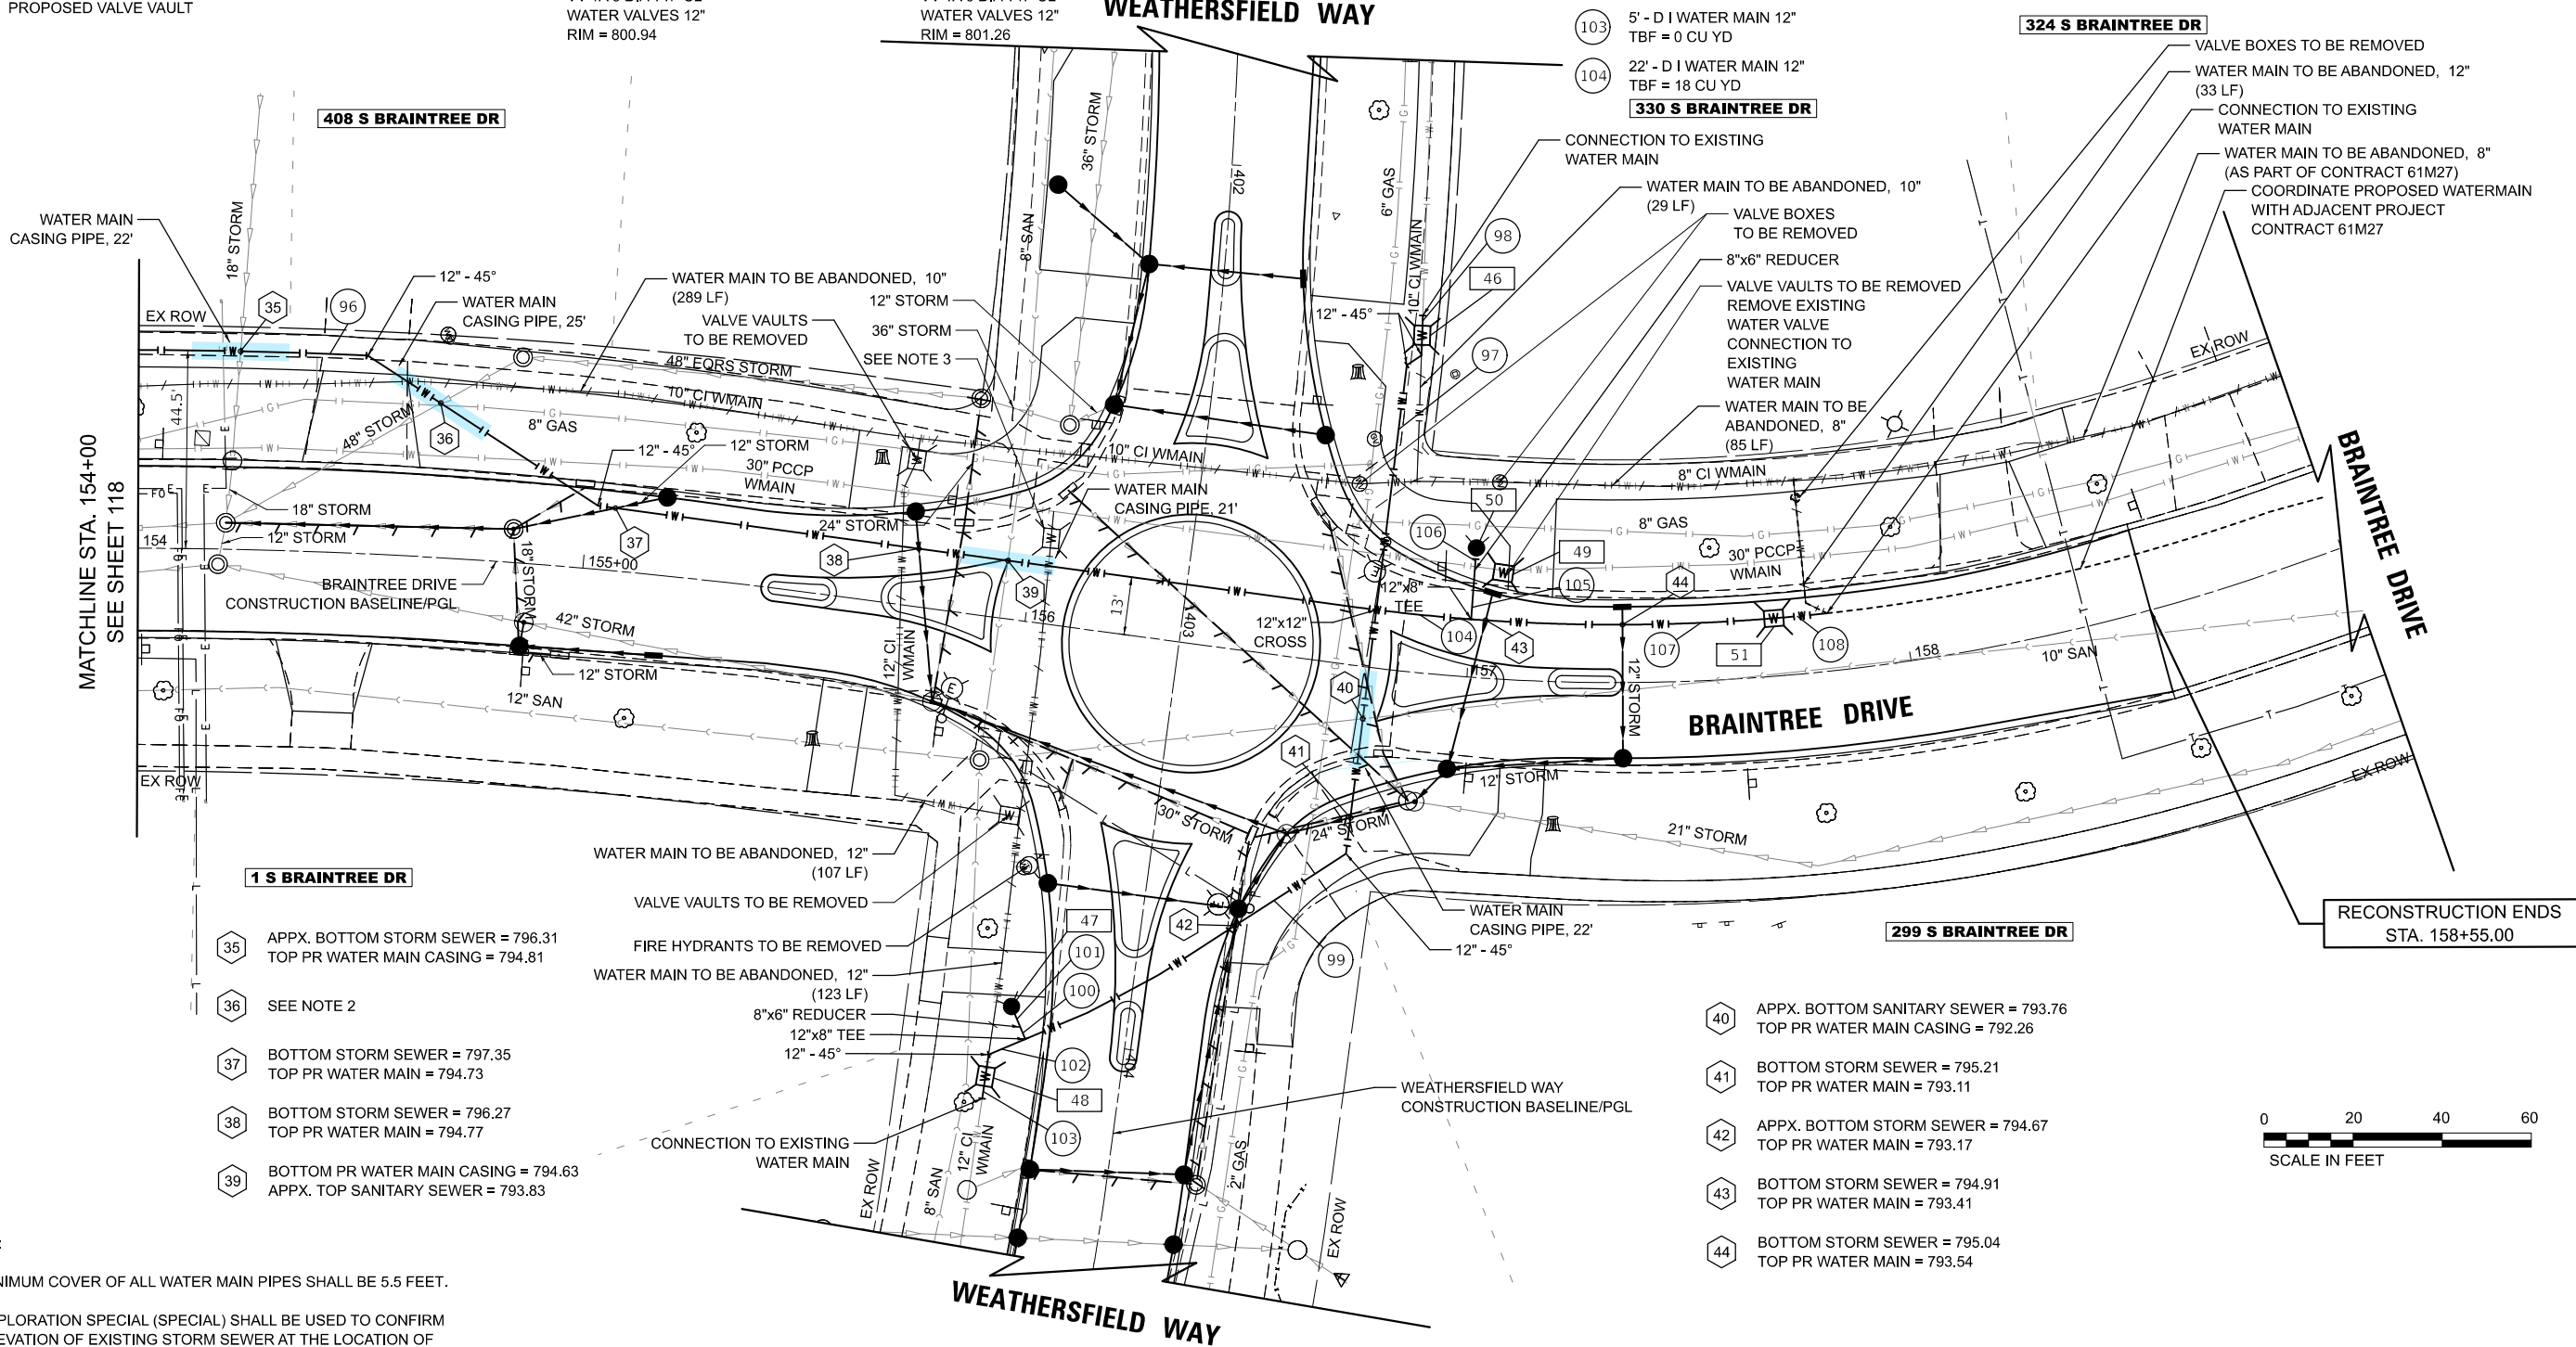

1 S BRAINTREE DR

- 35 APPX. BOTTOM STORM SEWER = 796.31
TOP PR WATER MAIN CASING = 794.81
36 SEE NOTE 2
37 BOTTOM STORM SEWER = 797.35
TOP PR WATER MAIN = 794.73
38 BOTTOM STORM SEWER = 796.27
TOP PR WATER MAIN = 794.77
39 BOTTOM PR WATER MAIN CASING = 794.63
APPX. TOP SANITARY SEWER = 793.83

299 S BRAINTREE DR

- 40 APPX. BOTTOM SANITARY SEWER = 793.76
TOP PR WATER MAIN CASING = 792.26
41 BOTTOM STORM SEWER = 795.21
TOP PR WATER MAIN = 793.11
42 APPX. BOTTOM STORM SEWER = 794.67
TOP PR WATER MAIN = 793.17
43 BOTTOM STORM SEWER = 794.91
TOP PR WATER MAIN = 793.41
44 BOTTOM STORM SEWER = 795.04
TOP PR WATER MAIN = 793.54



NOTE:


1. MINIMUM COVER OF ALL WATER MAIN PIPES SHALL BE 5.5 FEET.
2. EXPLORATION SPECIAL (SPECIAL) SHALL BE USED TO CONFIRM ELEVATION OF EXISTING STORM SEWER AT THE LOCATION OF CROSSING. IF PROPOSED WATER MAIN CAN BE INSTALLED MORE THAN 18" ABOVE THE STORM SEWER, WATER MAIN CASING SHALL NOT BE PROVIDED.
3. VAULT SHOWN BASED ON GIS INFORMATION. CONTRACTOR TO CONFIRM PRESENCE DURING REMOVAL & EXCAVATION OPERATIONS. IF PRESENT, REMOVE VAULT AS "VALVE VAULTS TO BE REMOVED".

STATE OF ILLINOIS
DEPARTMENT OF TRANSPORTATION

BRAINTREE DRIVE
WATER MAIN PLAN AND PROFILE

SCALE: 1"=20' SHEET 12 OF 14 SHEETS STA. 154+00.00 TO STA. 159+00.00

MUN RTE.	SECTION	COUNTY	TOTAL SHEETS	SHEET NO.
4029	23-00146-00-PV	COOK	315	119
CONTRACT NO. 61M26				
ILLINOIS FED. AID PROJECT				

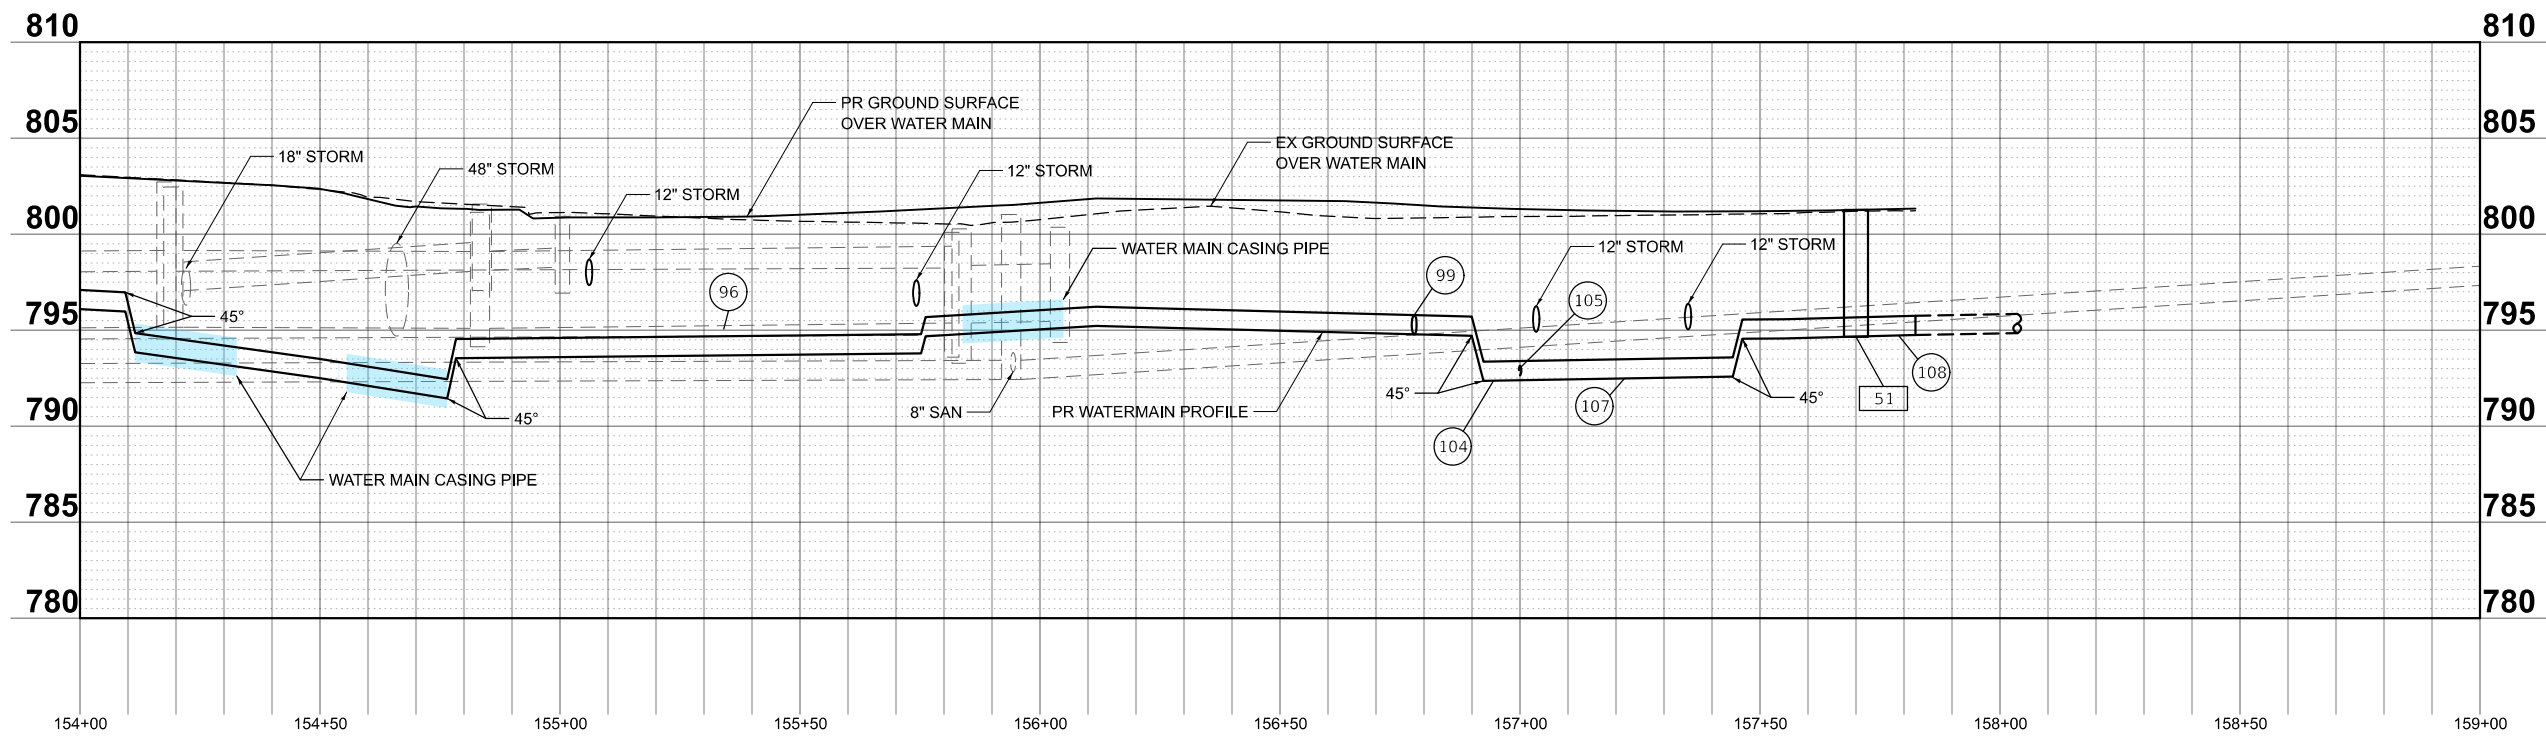

MODEL: Braintree - Sheet 12-2
FILE NAME: c:\bns\stl\tech-pw\patro.kravets\0140565\3983 Watermain.dgn

USER NAME = pk	DESIGNED -	AMP	REVISED -
	DRAWN -	AMP	REVISED -
	CHECKED -	PK	REVISED -
	DATE -	01/07/2026	REVISED -
PLOT DATE = 1/7/2026		DATE -	01/07/2026

STATE OF ILLINOIS
DEPARTMENT OF TRANSPORTATION


BRAINTREE DRIVE
WATER MAIN PLAN AND PROFILE

SCALE: 1"=20' SHEET 13 OF 14 SHEETS STA. 154+00.00 TO STA. 159+00.00

MUN RTE.	SECTION	COUNTY	TOTAL SHEETS	SHEET NO.
4029	23-00146-00-PV	COOK	315	120
CONTRACT NO. 61M26				
		ILLINOIS	FED. AID PROJECT	

LEGEND


- WATER MAIN CASING PIPE
- WATER MAIN CASING JACKING
- SUGGESTED PIT LOCATION
- STEEL CASING PIPE, BORED AND JACKED
- EXISTING VALVE VAULT
- EXISTING VALVE BOX
- PROPOSED VALVE VAULT

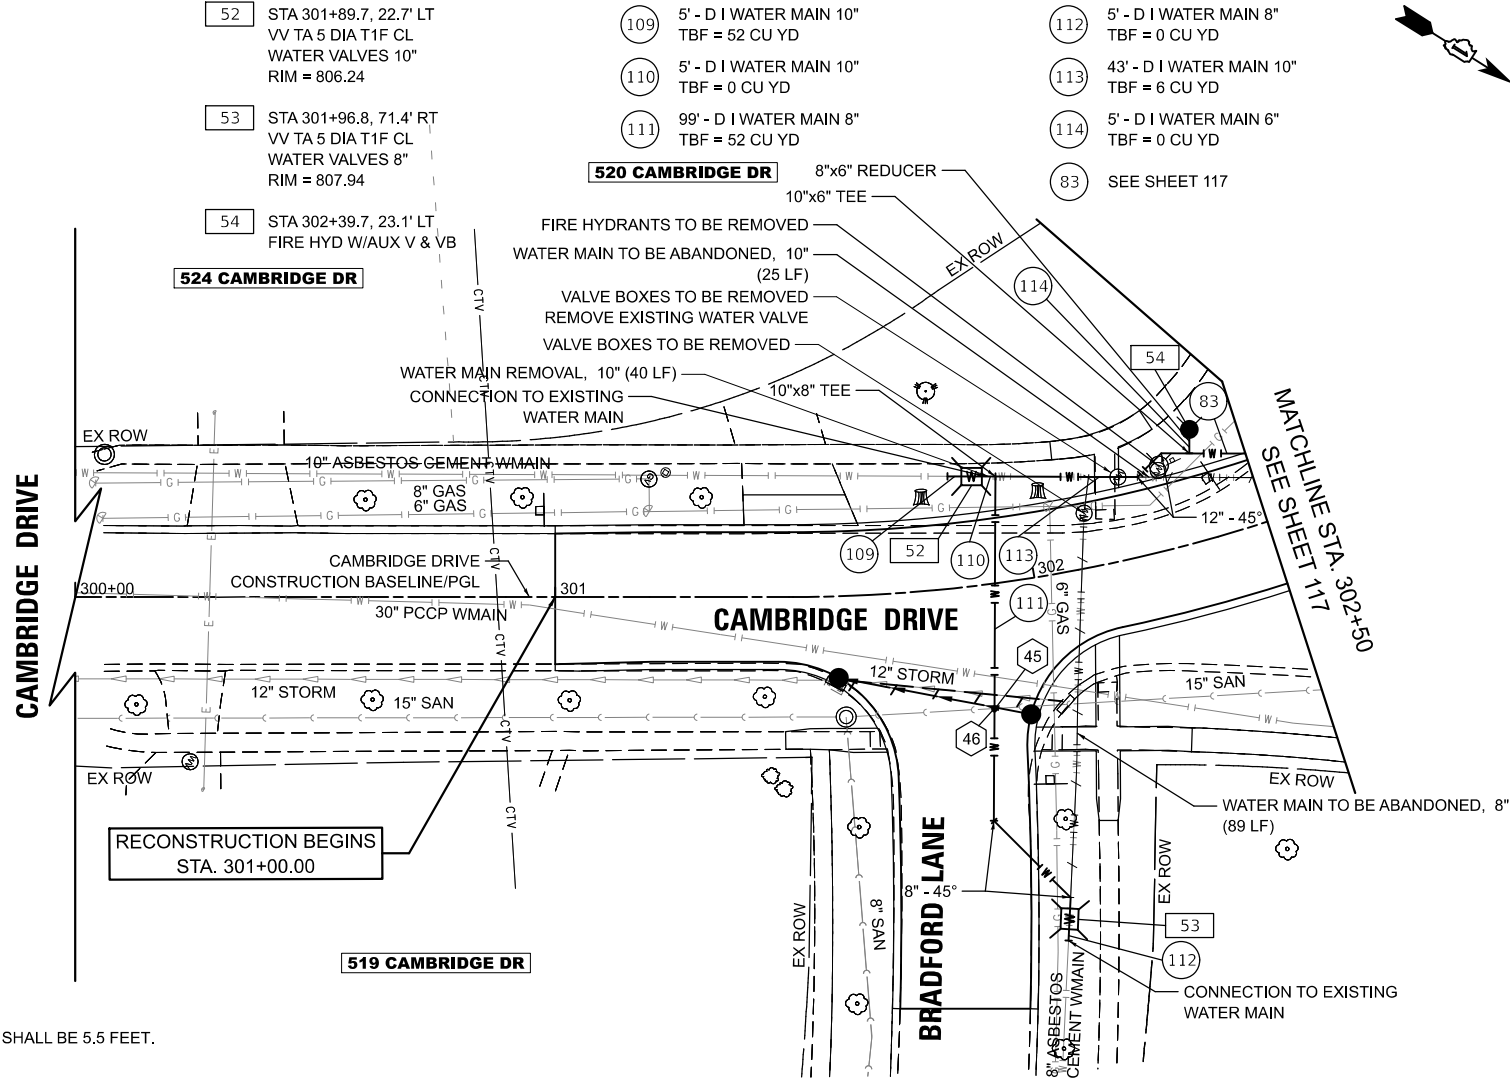

- 45 APPX. BOTTOM STORM SEWER = 801.08
TOP PR WATER MAIN = 799.58
- 46 BOTTOM PR WATER MAIN = 799.30
APPX. TOP SANITARY SEWER = 792.00

NOTE:

- 1. MINIMUM COVER OF ALL WATER MAIN PIPES SHALL BE 5.5 FEET.

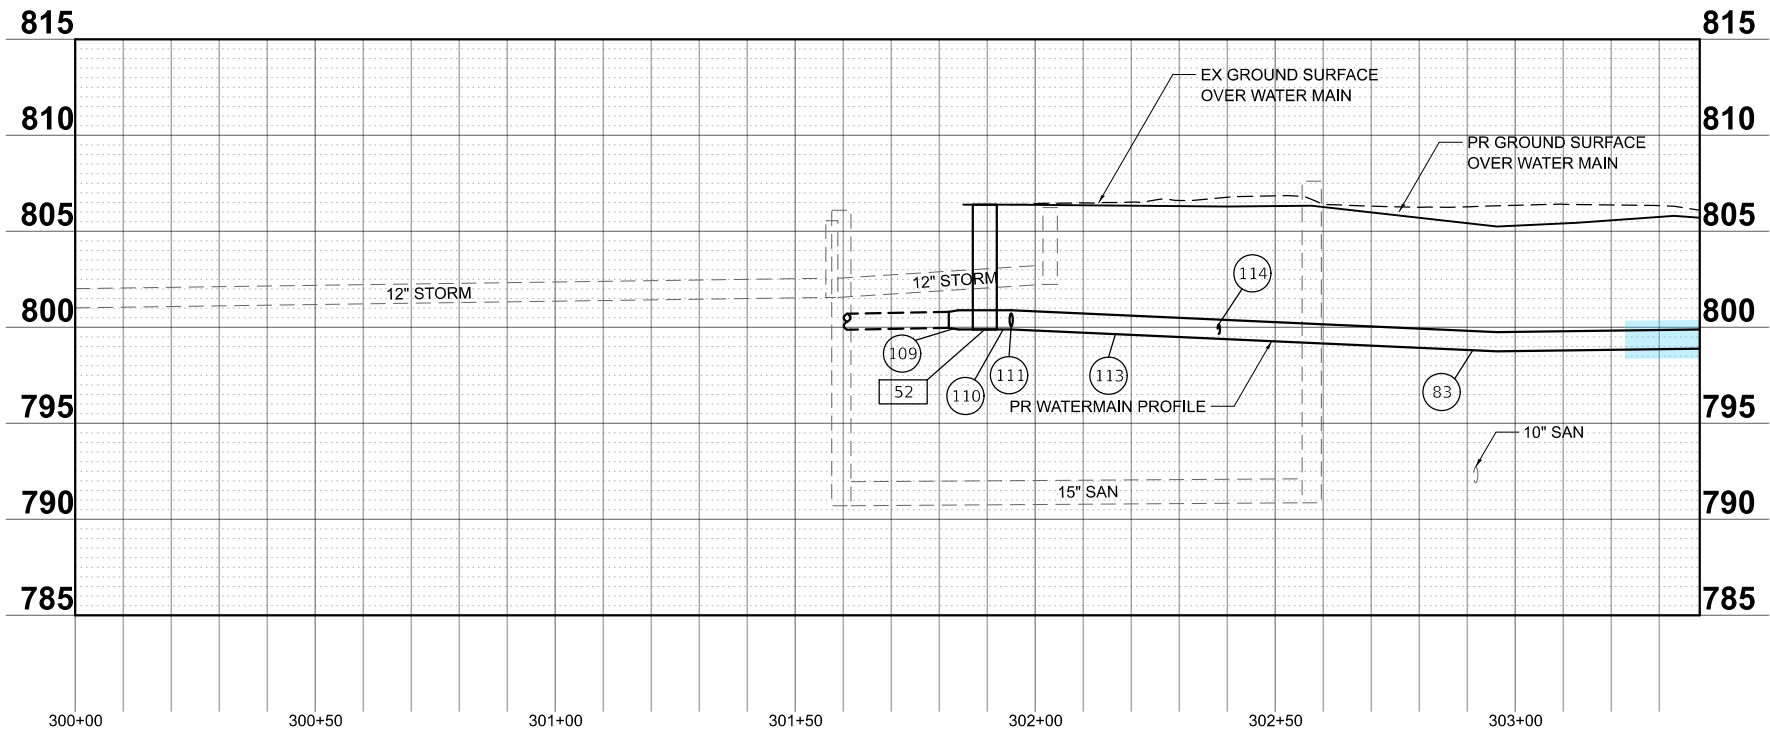

MODEL: Cambridge - Street 1 [Sheet]
FILE NAME: c:\bns\stl\tech-pw\pawr\c\kravets\0140565\3983 Watermain.dgn

USER NAME = pk	DESIGNED - AMP	REVISED -
	DRAWN - AMP	REVISED -
	CHECKED - PK	REVISED -
PLOT DATE = 1/7/2026	DATE - 01/07/2026	REVISED -


STATE OF ILLINOIS
DEPARTMENT OF TRANSPORTATION

CAMBRIDGE DRIVE
WATER MAIN PLAN AND PROFILE

SCALE: 1"=20' SHEET 14 OF 14 SHEETS STA. 300+00.00 TO STA. 302+50.00

MUN RTE.	SECTION	COUNTY	TOTAL SHEETS	SHEET NO.
4029	23-00146-00-PV	COOK	315	121
CONTRACT NO. 61M26				
ILLINOIS FED. AID PROJECT				

MODEL: Intersection Grading-1 (Sheet)
FILE NAME: c:\bms\sketch-pw\petro.kravets\01405673983 Intersection Grading.dgn

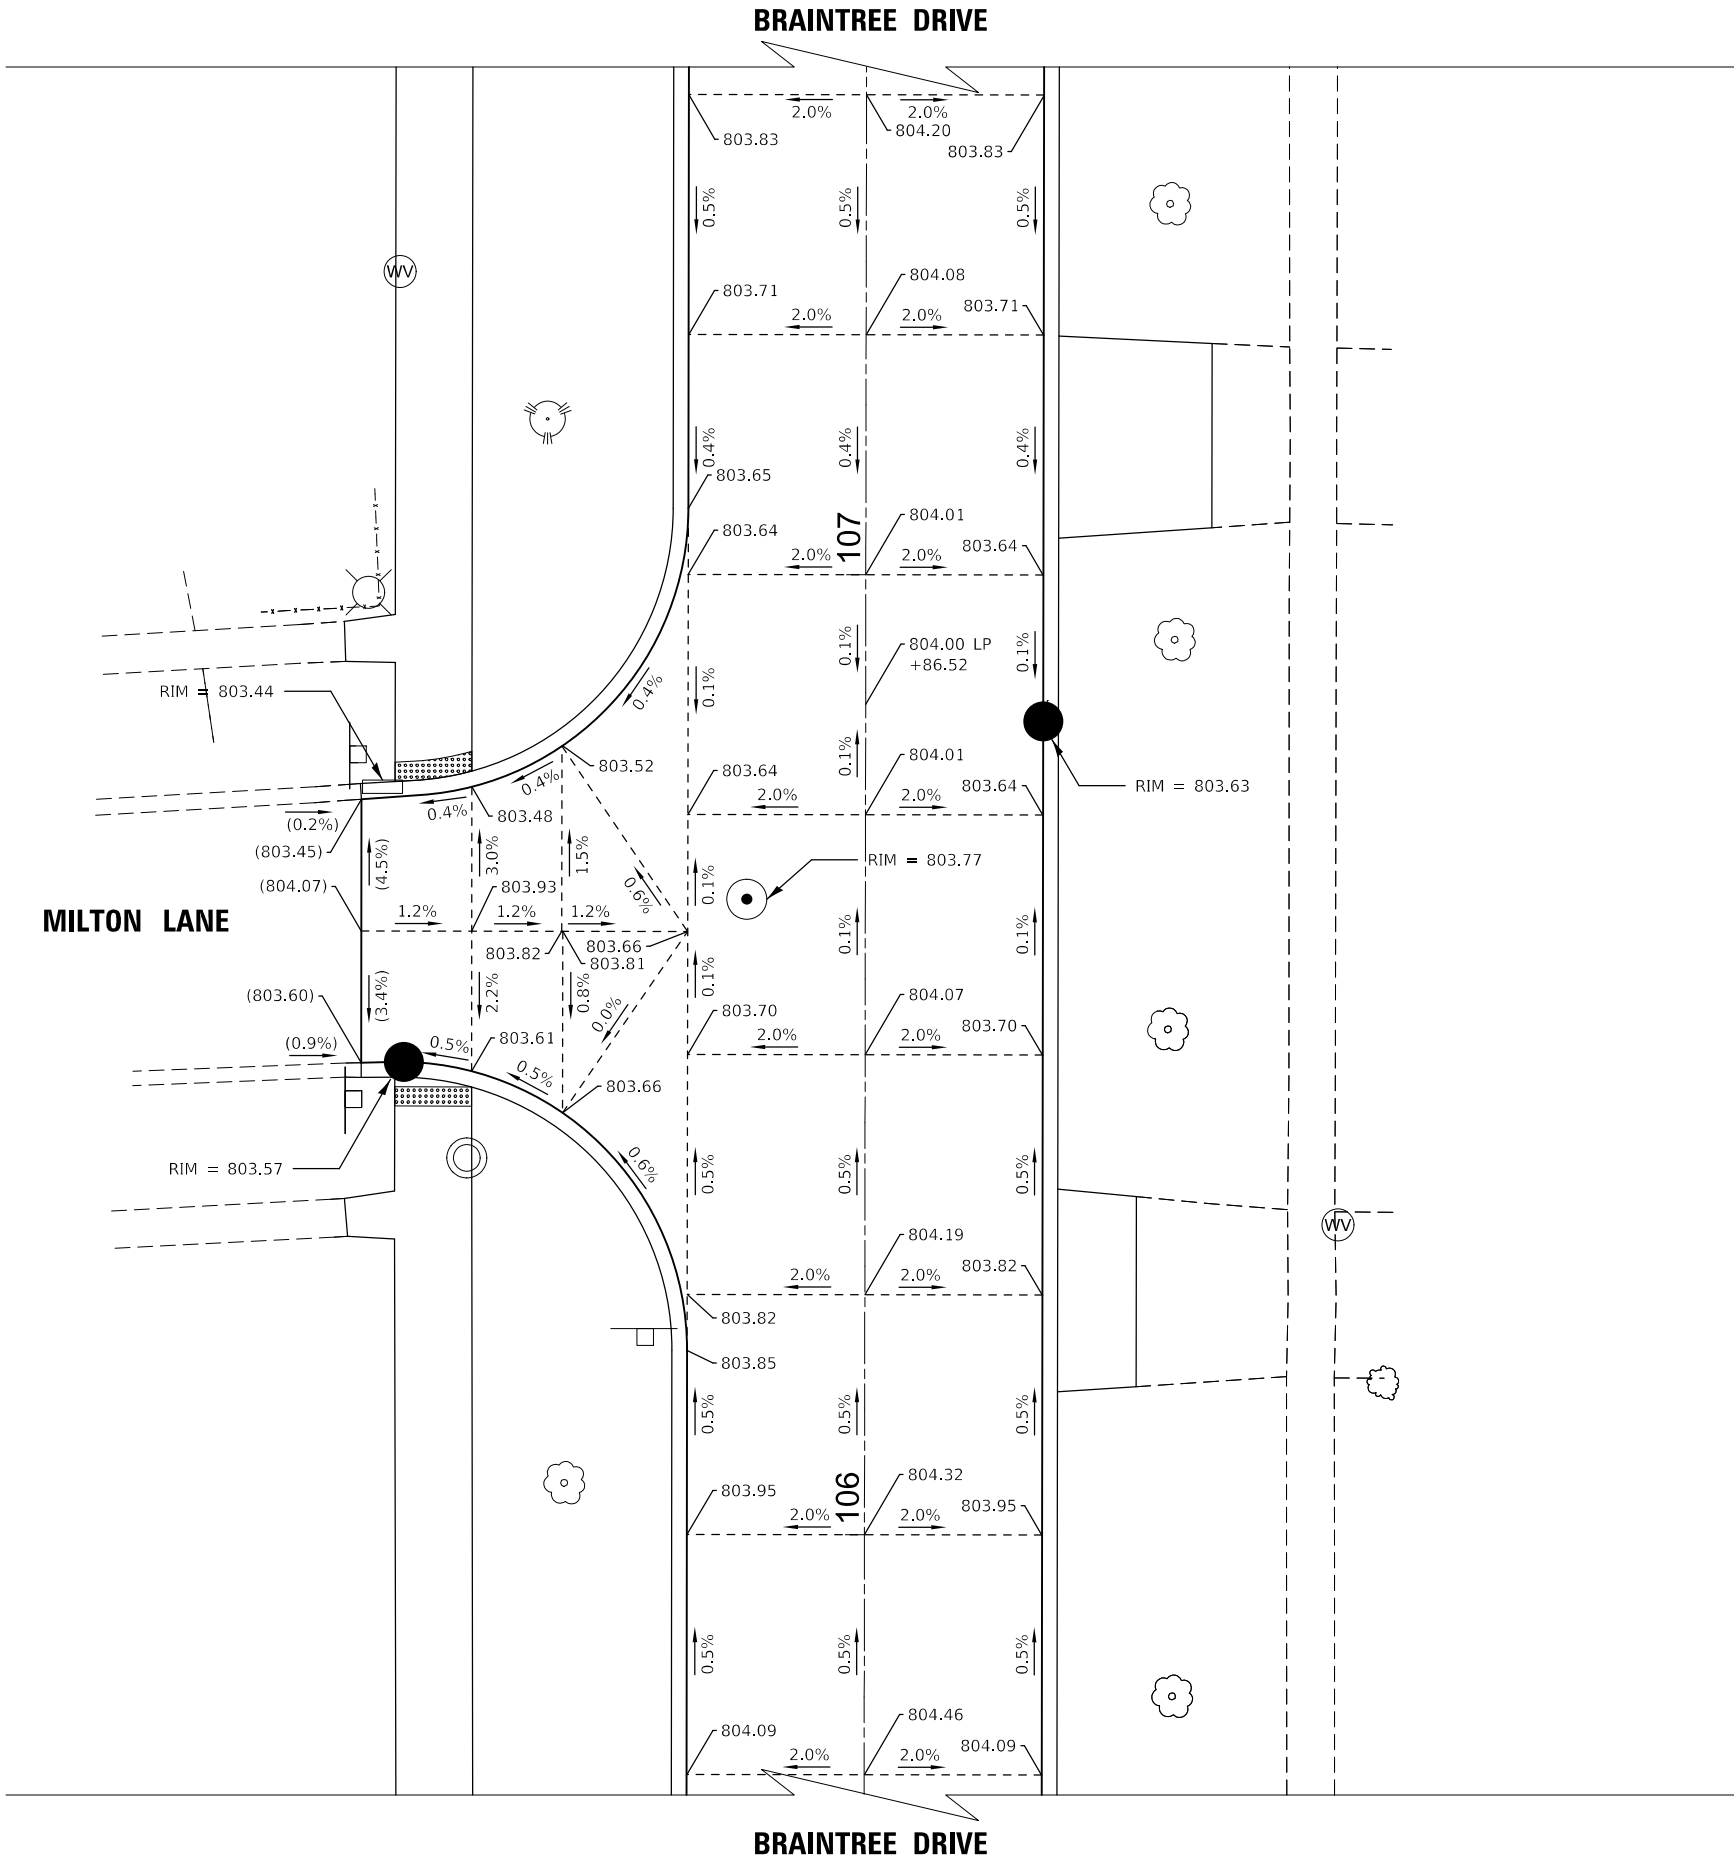

LEGEND

XXX.XX PROPOSED ELEVATION
(XXX.XX) EXISTING ELEVATION

NOTES

1) ELEVATIONS ARE GIVEN EVERY 25' (TYP).




PLOT DATE = 12/15/2025	USER NAME = pk	DESIGNED - AMP	REVISED -
		DRAWN - AMP	REVISED -
		CHECKED - PK	REVISED -
	DATE - 12/12/2025		REVISED -

**STATE OF ILLINOIS
DEPARTMENT OF TRANSPORTATION**

BRAINTREE DRIVE INTERSECTION GRADING PLAN - BRAINTREE DR AND MILTON LN			
SCALE:	SHEET 1	OF 10 SHEETS	STA. TO STA.

MUN RTE.	SECTION	COUNTY	TOTAL SHEETS	SHEET NO.
4029	23-00146-00-PV	COOK	315	122
CONTRACT NO. 61M26				
		ILLINOIS	FED. AID PROJECT	

MODEL: Intersection Grading-2 (Sheet)
FILE NAME: c:\bms\stltech-pw\petro.kravets\01405673983 Intersection Grading.dgn

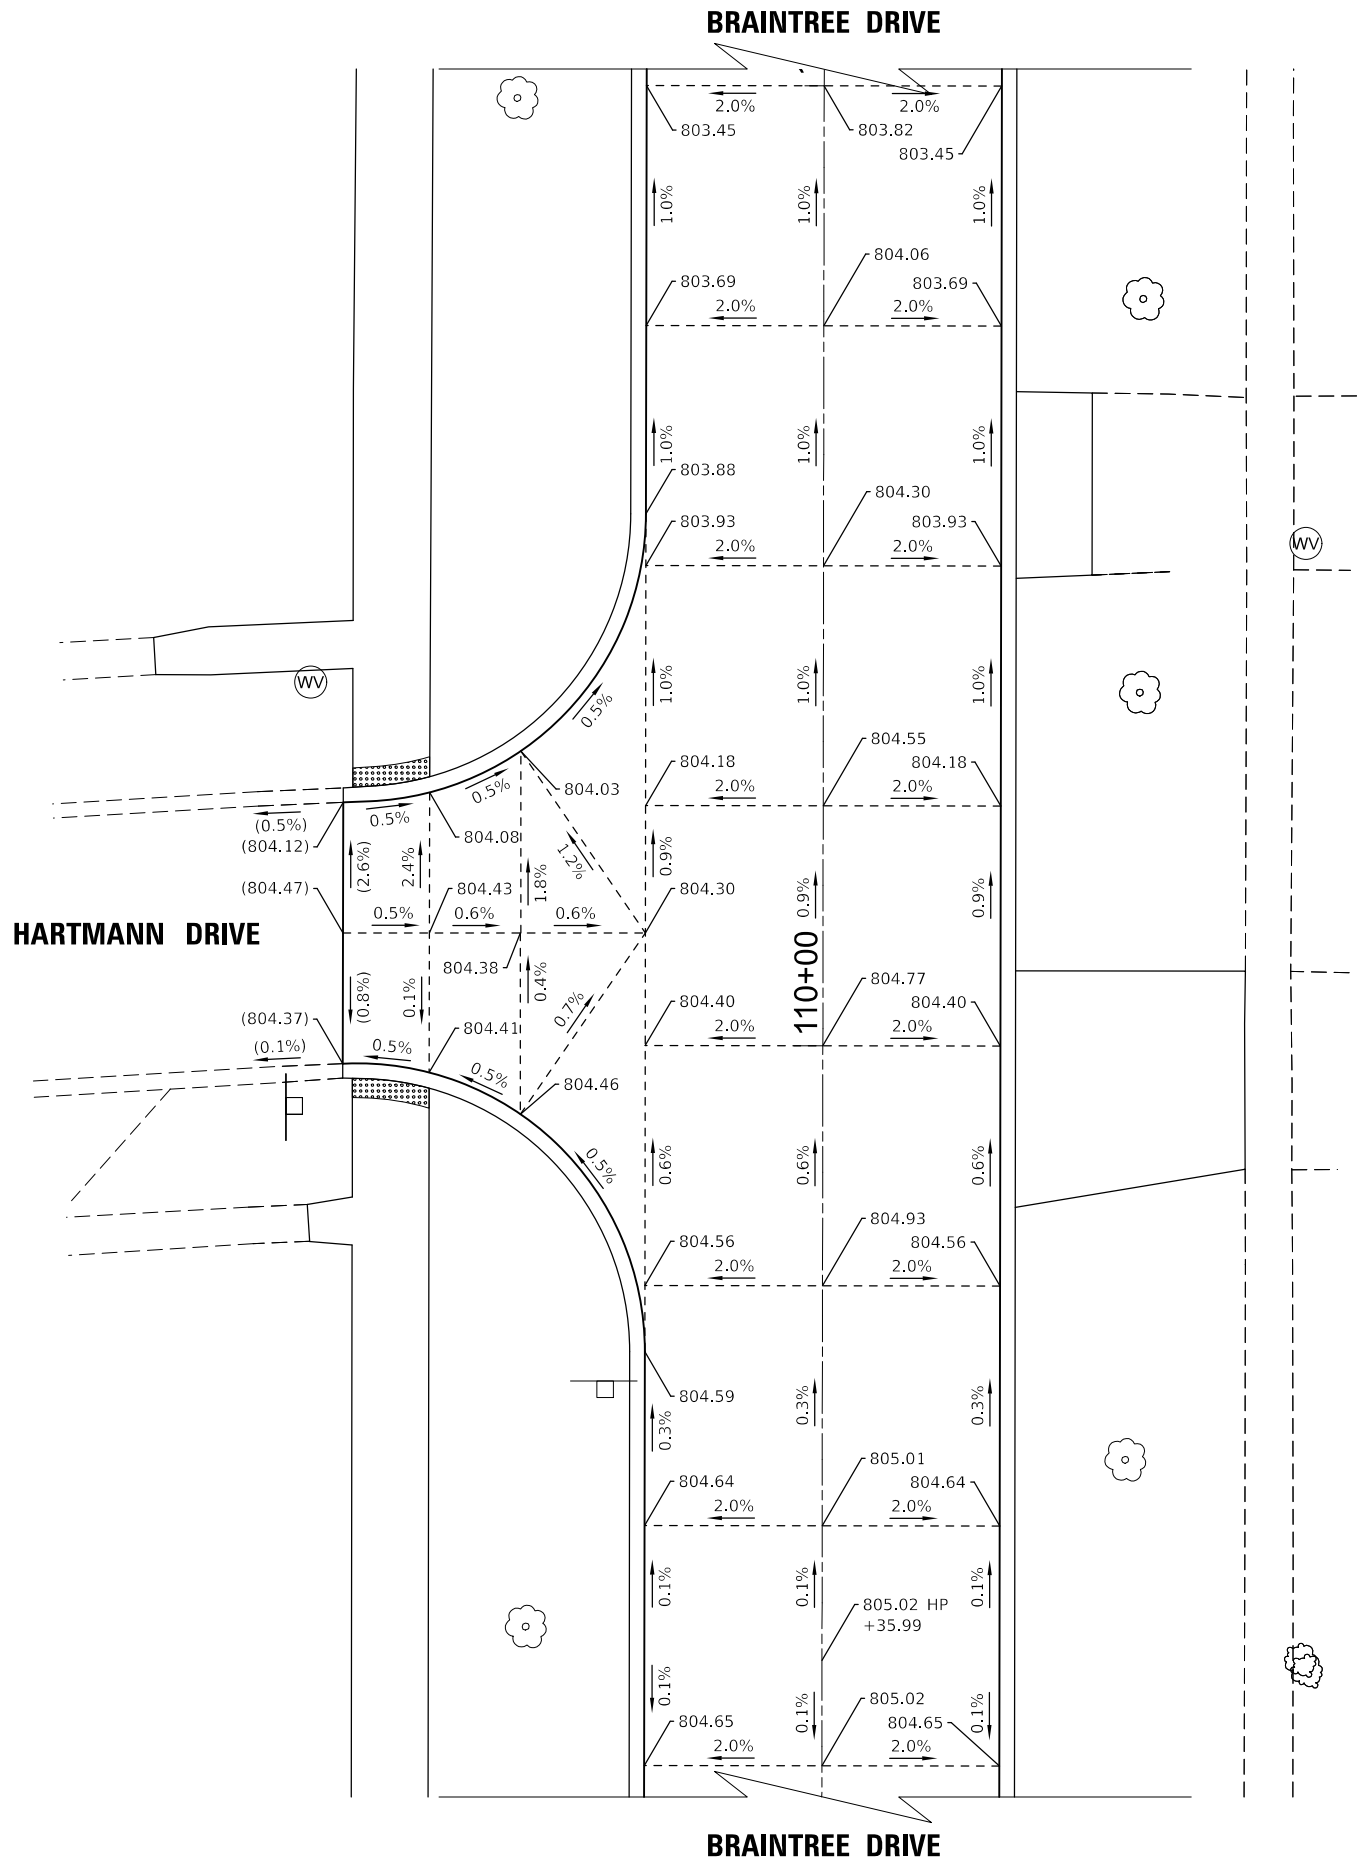

LEGEND

XXX.XX PROPOSED ELEVATION
(XXX.XX) EXISTING ELEVATION


NOTES

- 1) ELEVATIONS ARE GIVEN EVERY 25' (TYP).



	USER NAME = pk	DESIGNED - AMP	REVISED -	STATE OF ILLINOIS DEPARTMENT OF TRANSPORTATION	BRAINTREE DRIVE		MUN. RTE.	SECTION	COUNTY	TOTAL SHEETS	SHEET NO.
		DRAWN - AMP	REVISED -				4029	23-00146-00-PV	COOK	315	123
		CHECKED - PK	REVISED -		INTERSECTION GRADING PLAN - BRAINTREE DR AND HARTMANN DR		CONTRACT NO. 61M26				
	PLOT DATE = 12/11/2025	DATE - 12/12/2025	REVISED -		SCALE:		SHEET 2	OF 10	SHEETS	STA.	TO STA.
								ILLINOIS	FED. AID PROJECT		

MODEL: Intersection Grading-3 (Sheet)
FILE NAME: c:\bms\stltech-pv\petro.kravets\dd1405673983 Intersection Grading.dgn

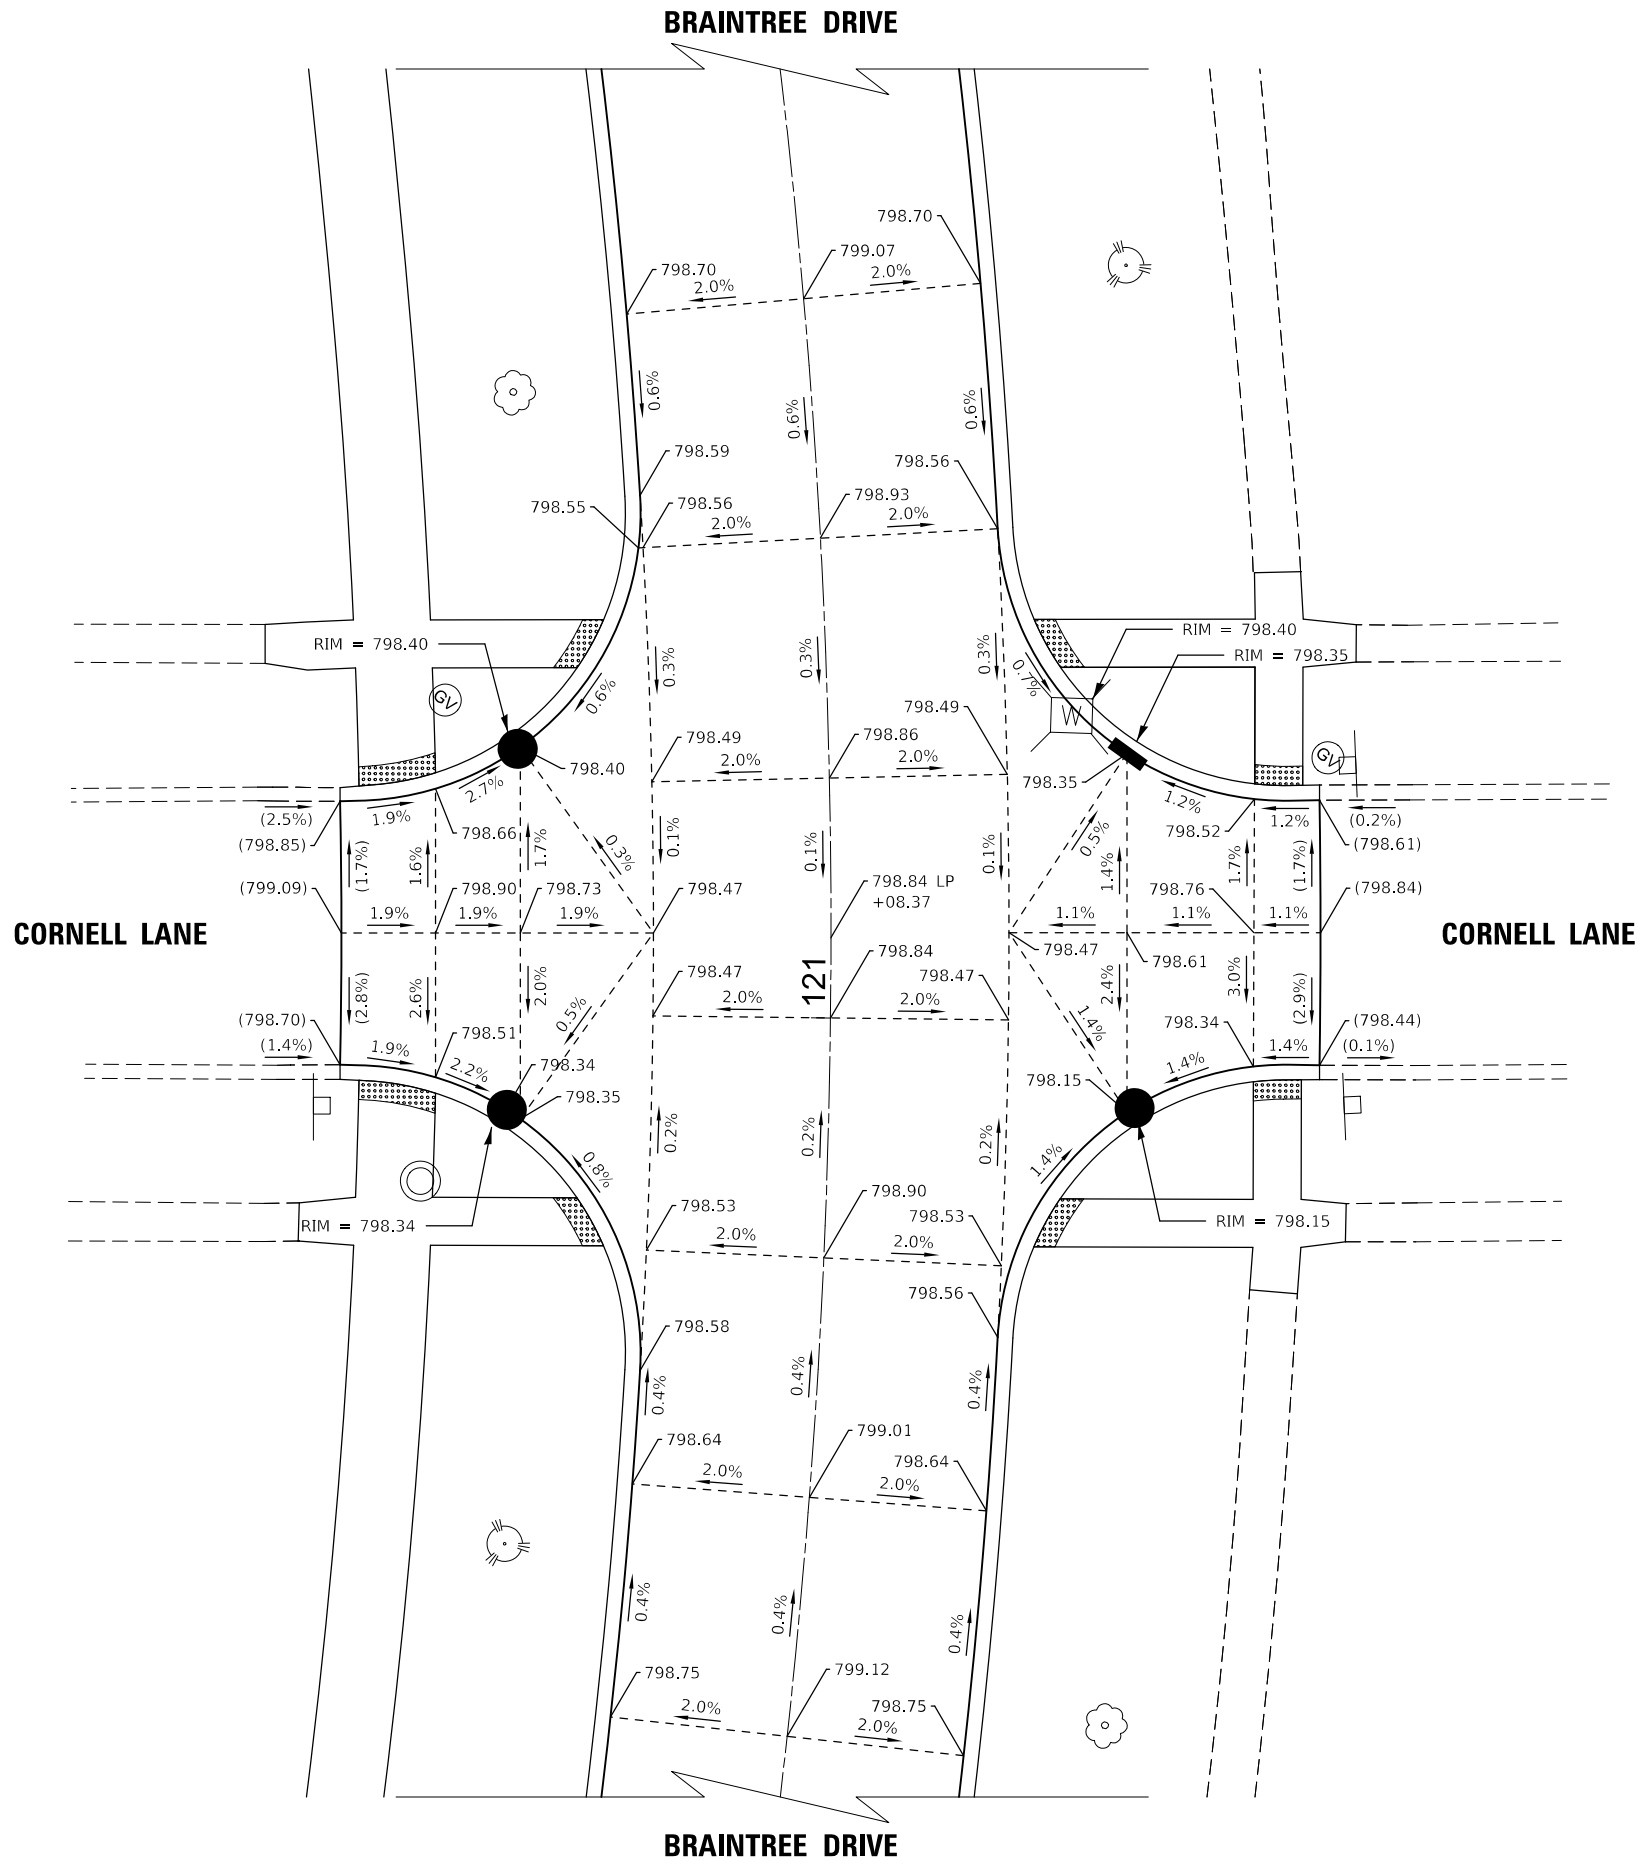

LEGEND

XXX.XX PROPOSED ELEVATION
(XXX.XX) EXISTING ELEVATION

NOTES

1) ELEVATIONS ARE GIVEN EVERY 25' (TYP).



PLOT DATE = 12/15/2025	USER NAME = pk	DESIGNED - AMP	REVISED -
		DRAWN - AMP	REVISED -
		CHECKED - PK	REVISED -
	DATE - 12/12/2025		REVISED -


STATE OF ILLINOIS
DEPARTMENT OF TRANSPORTATION

BRAINTREE DRIVE
INTERSECTION GRADING PLAN - BRAINTREE DR AND CORNELL LN

SCALE: SHEET 3 OF 10 SHEETS STA. TO STA.

MUN RTE.	SECTION	COUNTY	TOTAL SHEETS	SHEET NO.
4029	23-00146-00-PV	COOK	315	124
CONTRACT NO. 61M26				
ILLINOIS FED. AID PROJECT				

MODEL: Intersection Grading-4 (Sheet)
FILE NAME: c:\bms\sketch-pw\petro.kravets\01405673993 Intersection Grading.dgn

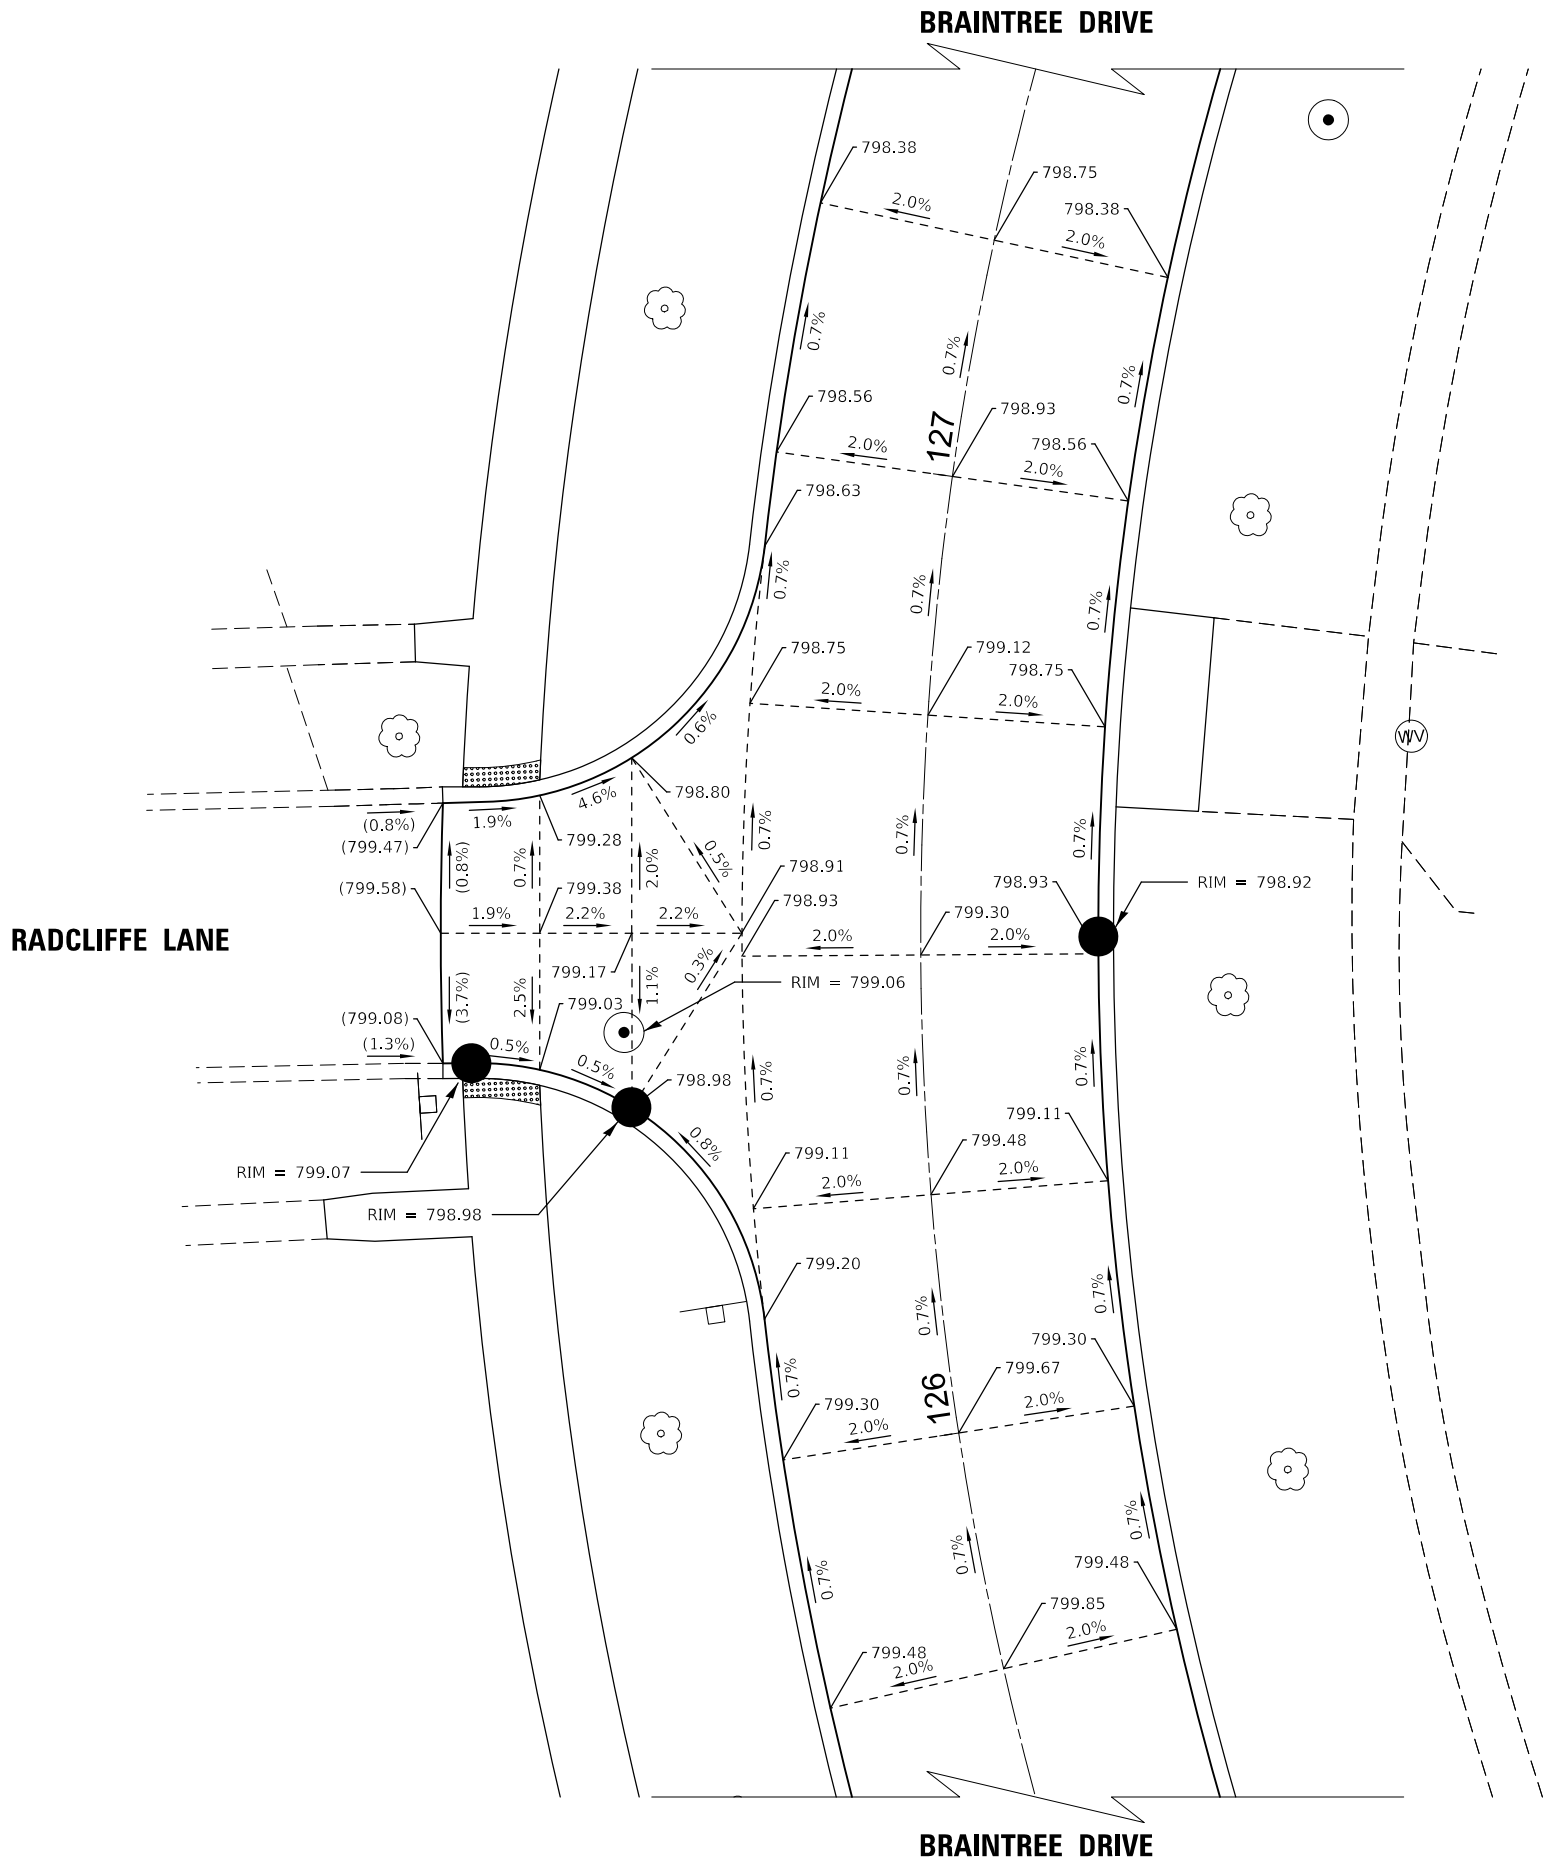

LEGEND

XXX.XX PROPOSED ELEVATION
(XXX.XX) EXISTING ELEVATION

NOTES

- 1) ELEVATIONS ARE GIVEN EVERY 25' (TYP).



	USER NAME = pk	DESIGNED - AMP	REVISED -
		DRAWN - AMP	REVISED -
		CHECKED - PK	REVISED -
	PLOT DATE = 12/15/2025	DATE - 12/12/2025	REVISED -


STATE OF ILLINOIS
DEPARTMENT OF TRANSPORTATION

BRAINTREE DRIVE
INTERSECTION GRADING PLAN - BRAINTREE DR AND RADCLIFFE LN

SCALE: SHEET 4 OF 10 SHEETS STA. TO STA.

MUN RTE.	SECTION	COUNTY	TOTAL SHEETS	SHEET NO.
4029	23-00146-00-PV	COOK	315	125
CONTRACT NO. 61M26				
ILLINOIS FED. AID PROJECT				

MODEL: Intersection Grading-7 (Sheet)
FILE NAME: c:\bms\stl\tech-pw\petro_kraves\dd140567\3983 Intersection Grading.dgn

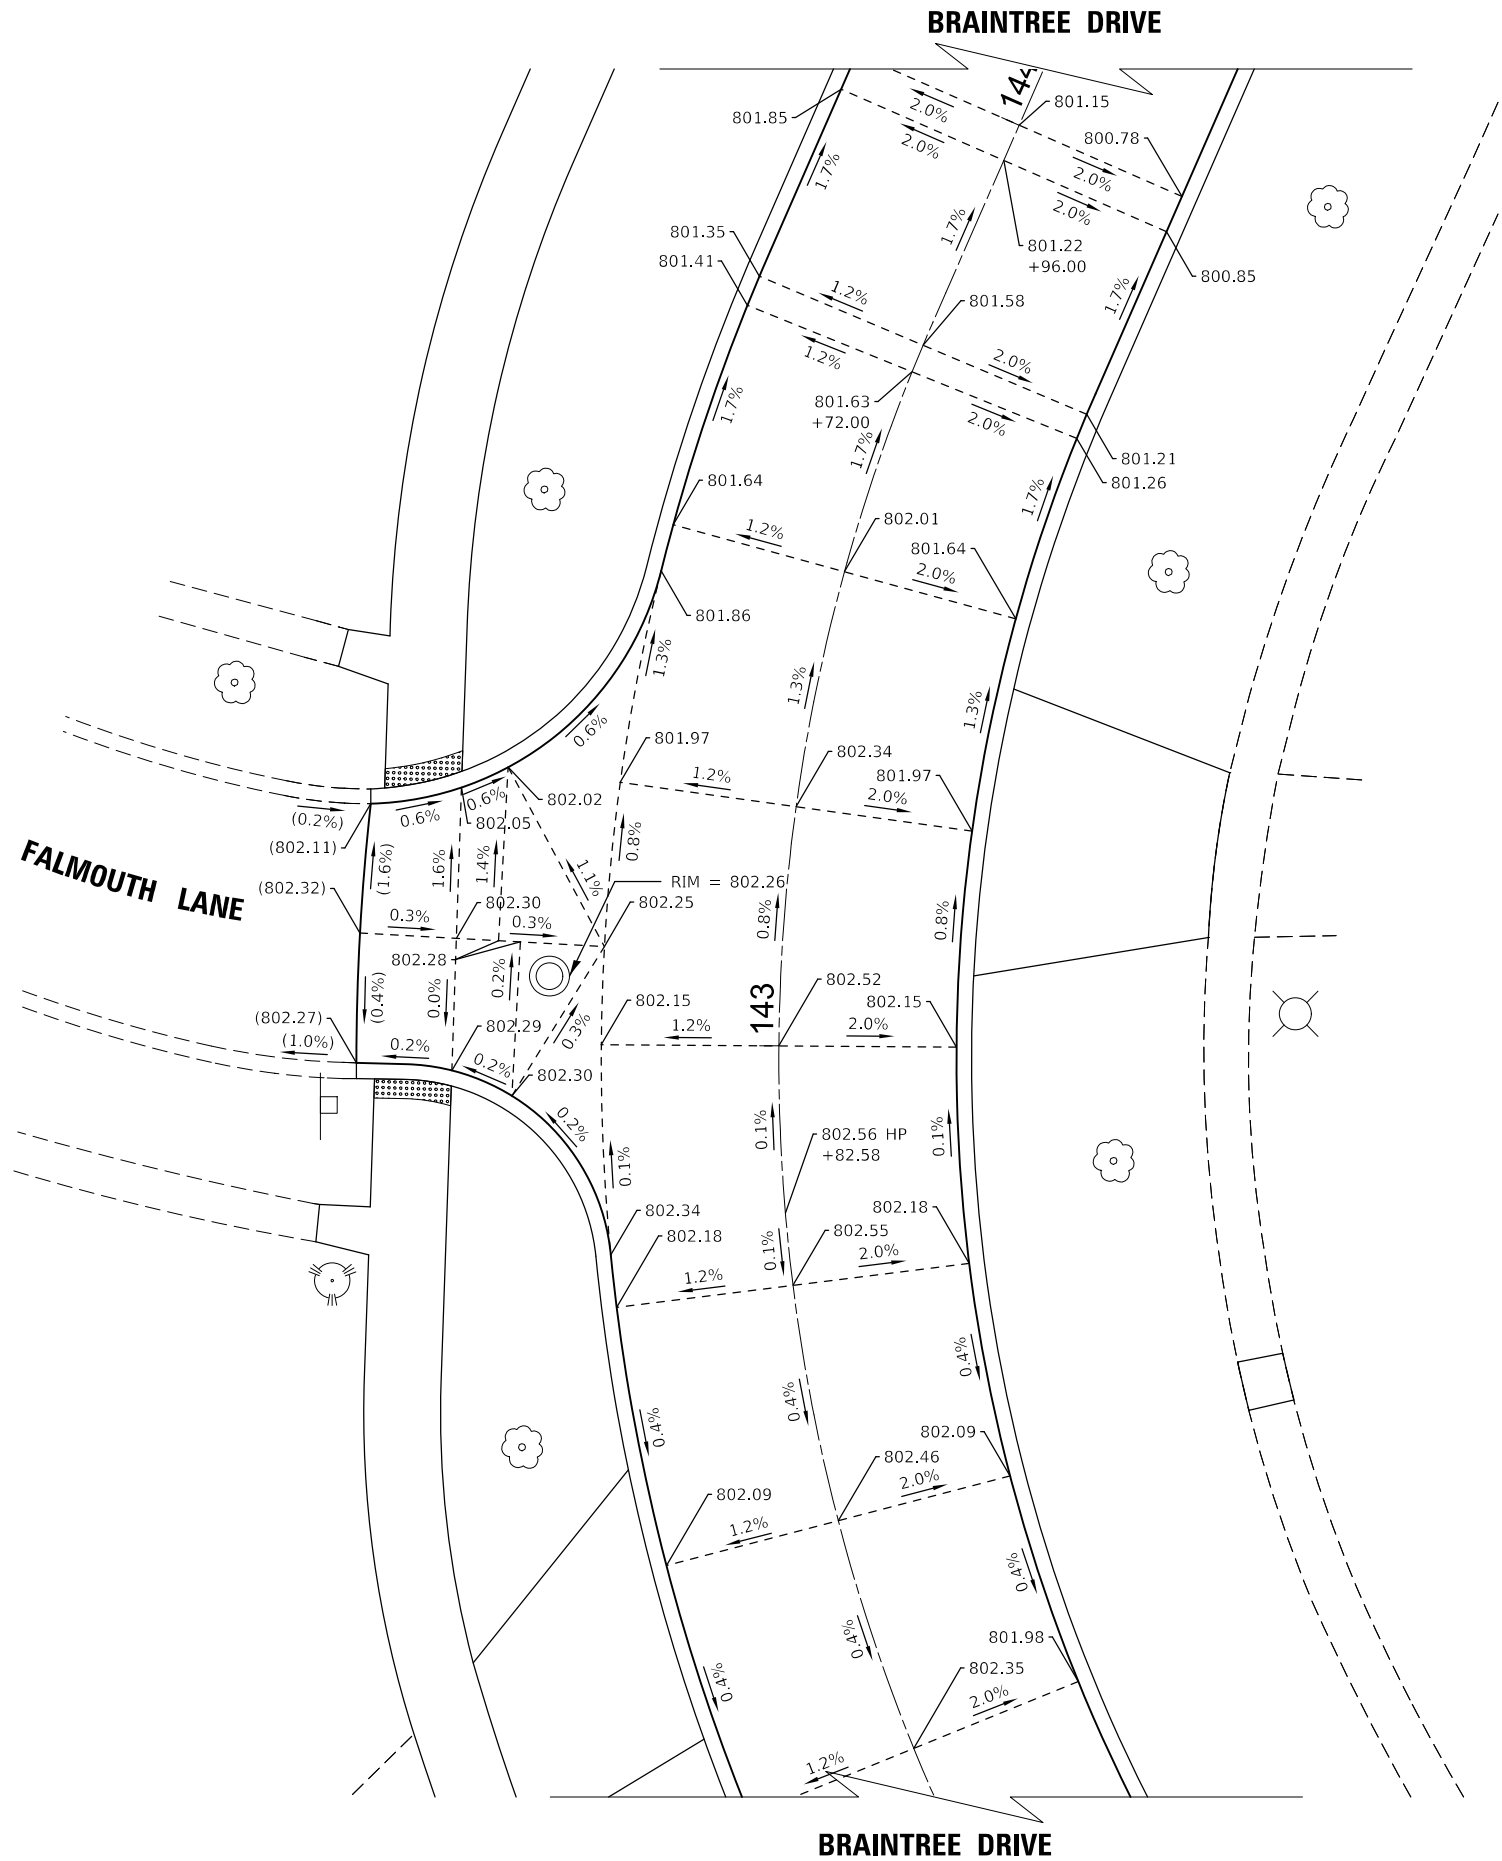

LEGEND

XXX.XX PROPOSED ELEVATION
(XXX.XX) EXISTING ELEVATION

NOTES

1) ELEVATIONS ARE GIVEN EVERY 25' (TYP).



USER NAME = pk	DESIGNED - AMP	REVISED -
	DRAWN - AMP	REVISED -
	CHECKED - PK	REVISED -
	DATE - 12/12/2025	REVISED -


STATE OF ILLINOIS
DEPARTMENT OF TRANSPORTATION

BRAINTREE DRIVE
INTERSECTION GRADING PLAN - BRAINTREE DR AND FALMOUTH LN

SCALE: SHEET 7 OF 10 SHEETS STA. TO STA.

MUN RTE.	SECTION	COUNTY	TOTAL SHEETS	SHEET NO.
4029	23-00146-00-PV	COOK	315	128
CONTRACT NO. 61M26				
ILLINOIS FED. AID PROJECT				

MODEL: Intersection Grading-S (Sheet)
FILE NAME: c:\bms\stl\tech-plot\petro.kravets\01405673993 Intersection Grading.dgn

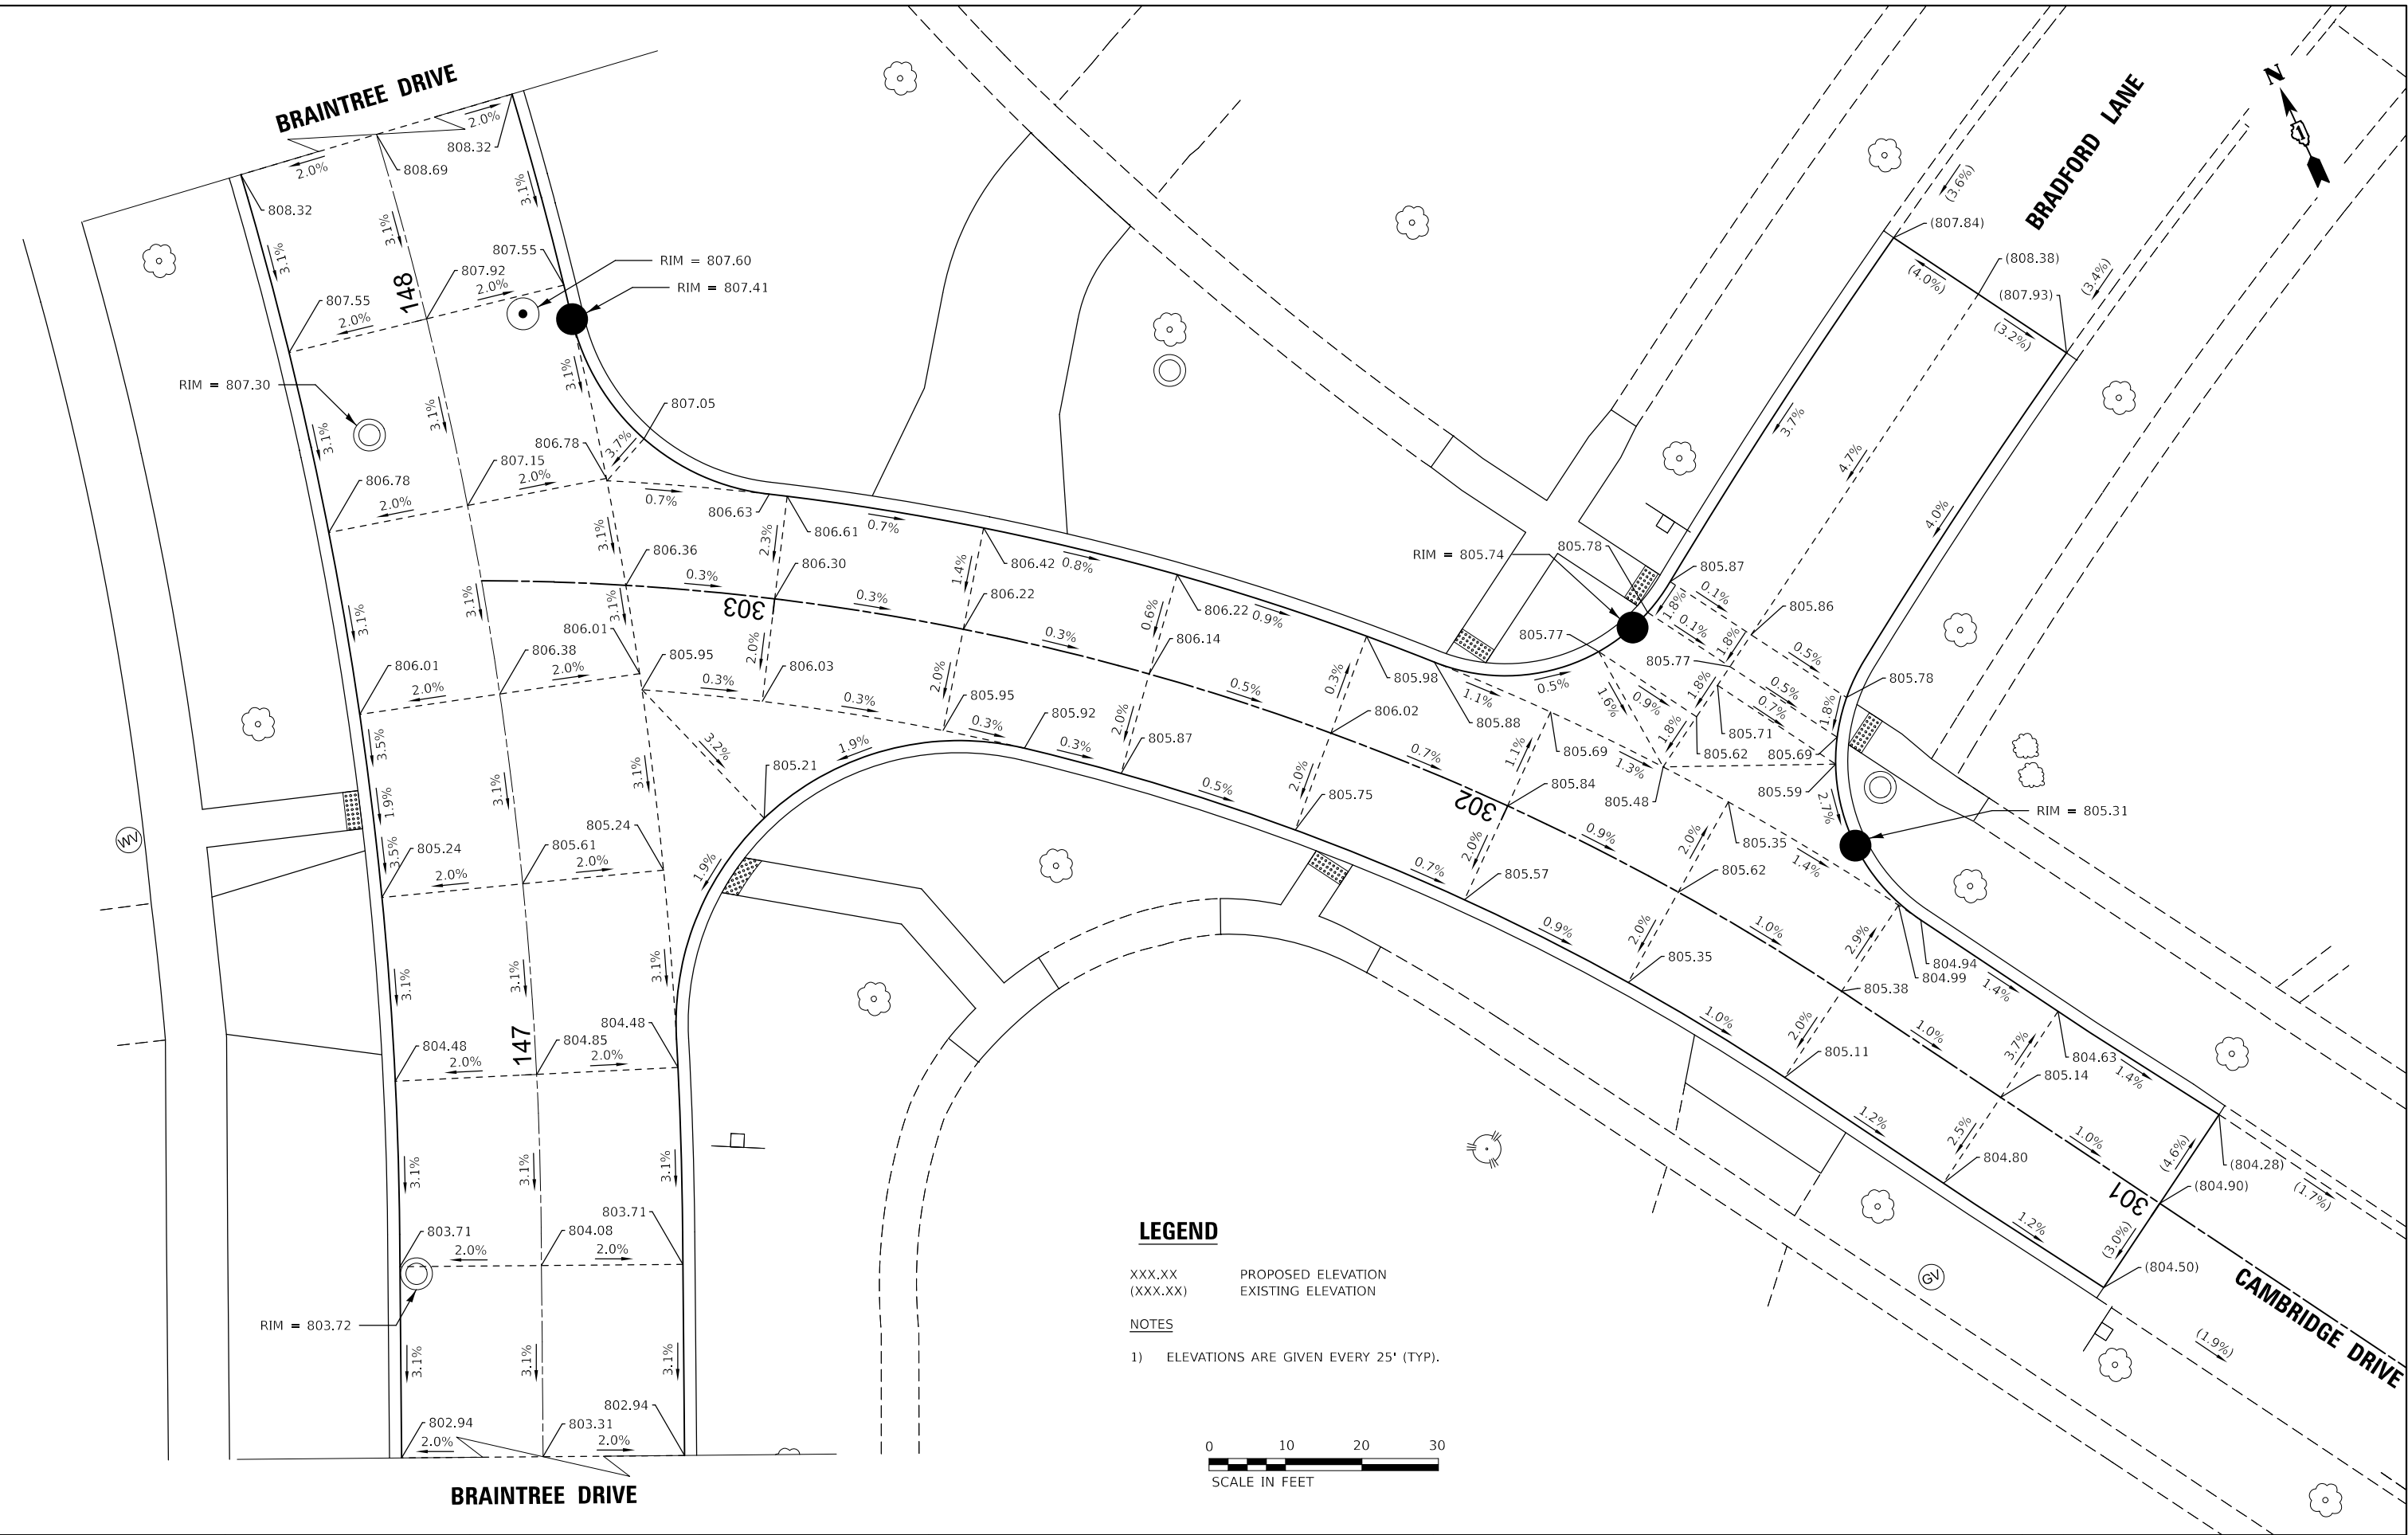

USER NAME	= pk	DESIGNED	- AMP	REVISED	-
		DRAWN	- AMP	REVISED	-
		CHECKED	- PK	REVISED	-
PLOT DATE	= 12/15/2025	DATE	- 12/12/2025	REVISED	-

STATE OF ILLINOIS
DEPARTMENT OF TRANSPORTATION


0 10 20 30
SCALE IN FEET

BRAINTREE DRIVE
INTERSECTION GRADING PLAN - BRAINTREE DR AND CAMBRIDGE DR

SCALE: SHEET 8 OF 10 SHEETS STA. TO STA.

MUN RTE.	SECTION	COUNTY	TOTAL SHEETS	SHEET NO.
4029	23-00146-00-PV	COOK	315	129
CONTRACT NO. 61M26				
ILLINOIS FED. AID PROJECT				

MODEL: Intersection Grading-9 (Sheet)
FILE NAME: c:\bms\stl\tech-pw\petro_kraves\dd1405673983 Intersection Grading.dgn

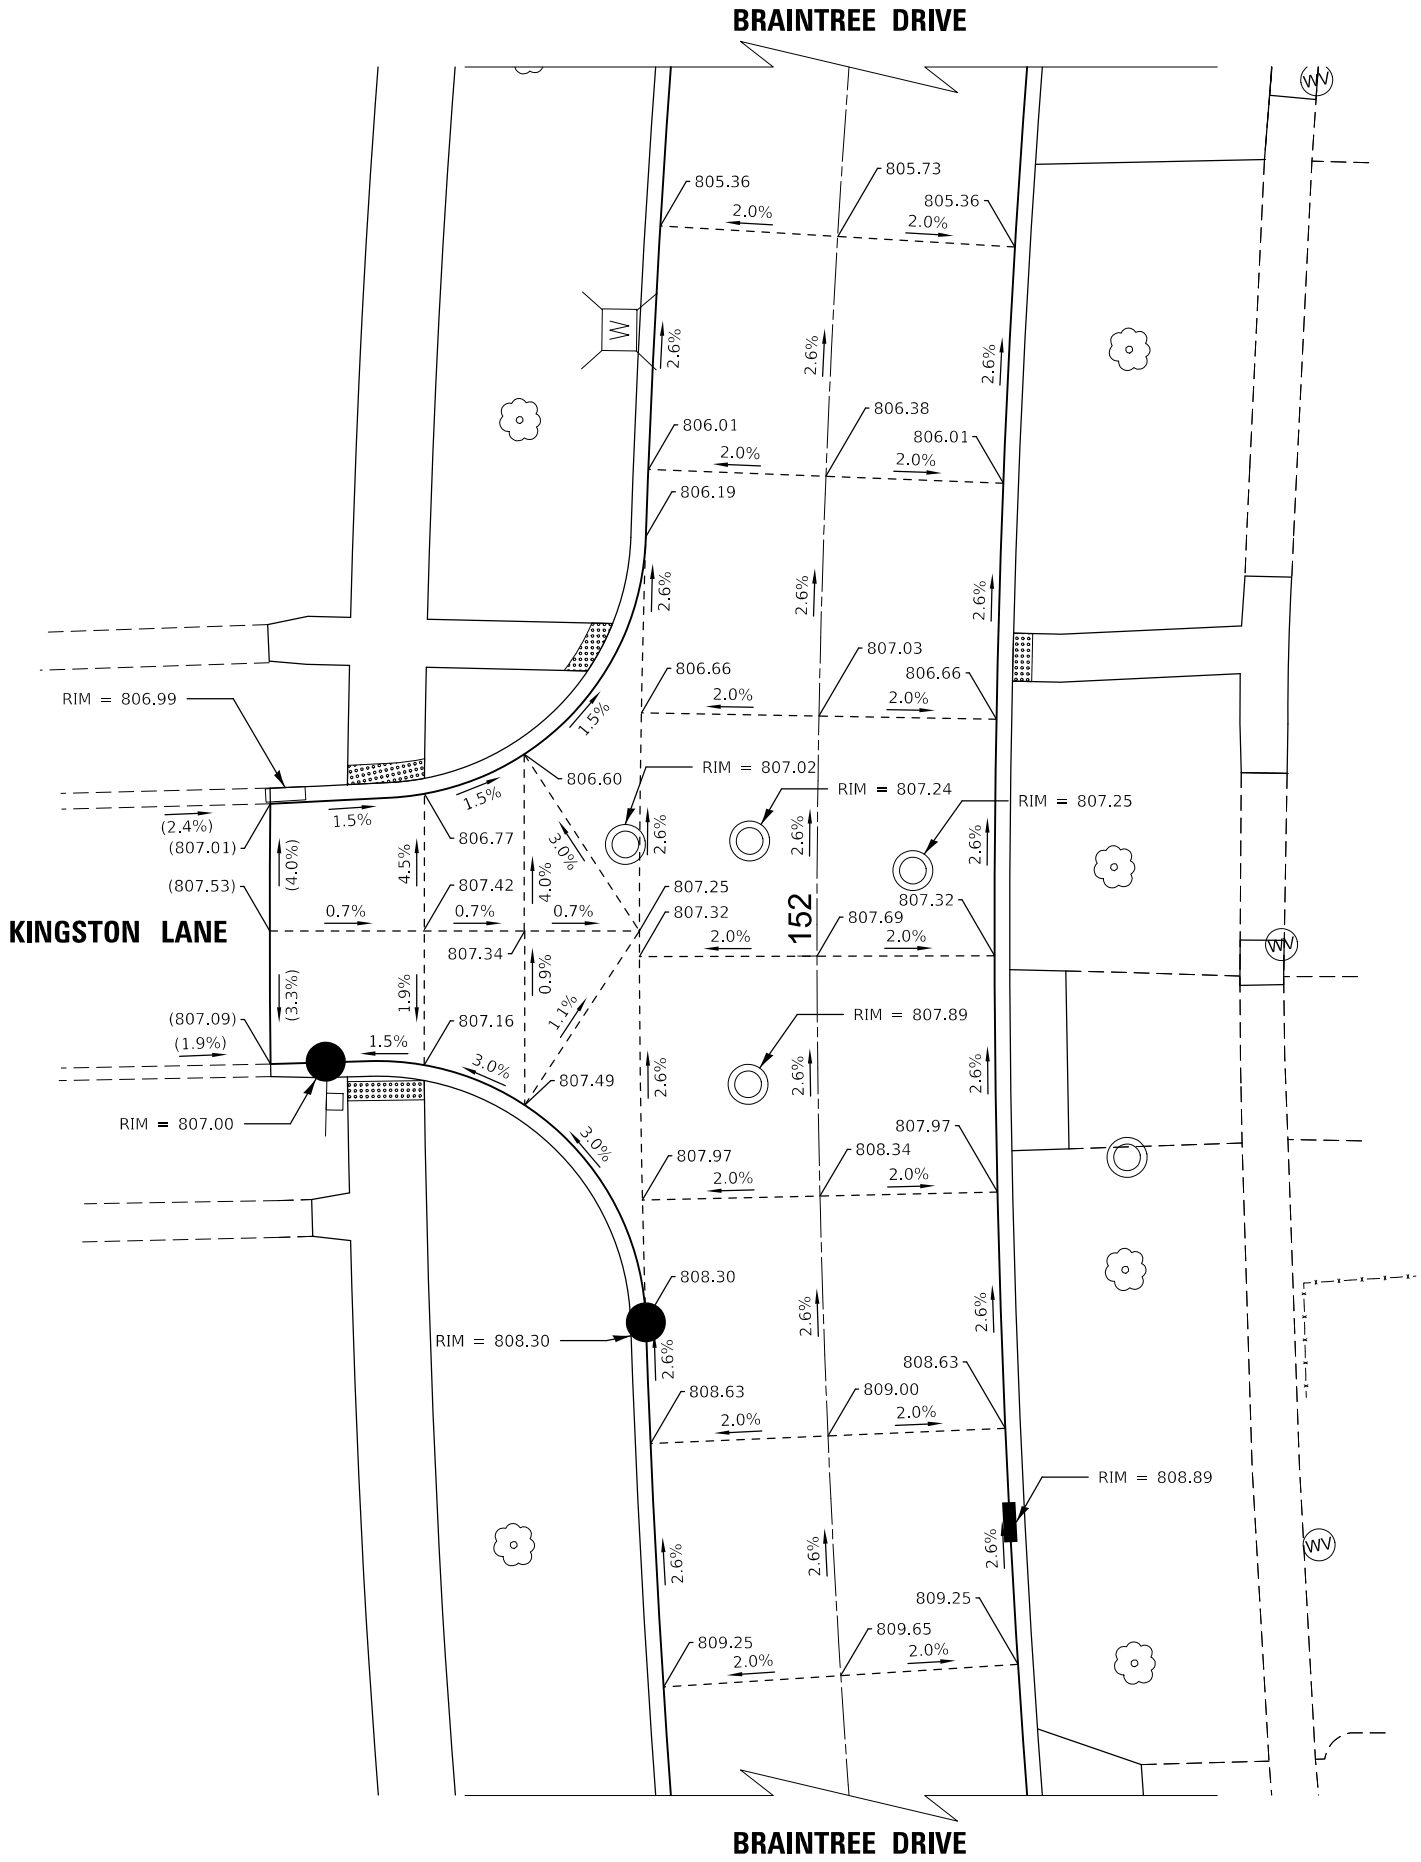

LEGEND

XXX.XX PROPOSED ELEVATION
(XXX.XX) EXISTING ELEVATION

NOTES

- 1) ELEVATIONS ARE GIVEN EVERY 25' (TYP).



PLOT DATE = 12/15/2025	USER NAME = pk	DESIGNED - AMP	REVISED -
		DRAWN - AMP	REVISED -
		CHECKED - PK	REVISED -
	DATE - 12/12/2025		REVISED -

STATE OF ILLINOIS
DEPARTMENT OF TRANSPORTATION


BRAINTREE DRIVE
INTERSECTION GRADING PLAN - BRAINTREE DR AND KINGSTON LN

SCALE: SHEET 9 OF 10 SHEETS STA. TO STA.

MUN RTE.	SECTION	COUNTY	TOTAL SHEETS	SHEET NO.
4029	23-00146-00-PV	COOK	315	130
CONTRACT NO. 61M26				
ILLINOIS FED. AID PROJECT				



MODEL: ADA-1 [Sheet]
FILE NAME: c:\bns\citytech-pw\petro.kravets\0140567\3993 ADA Curb Ramps.dgn

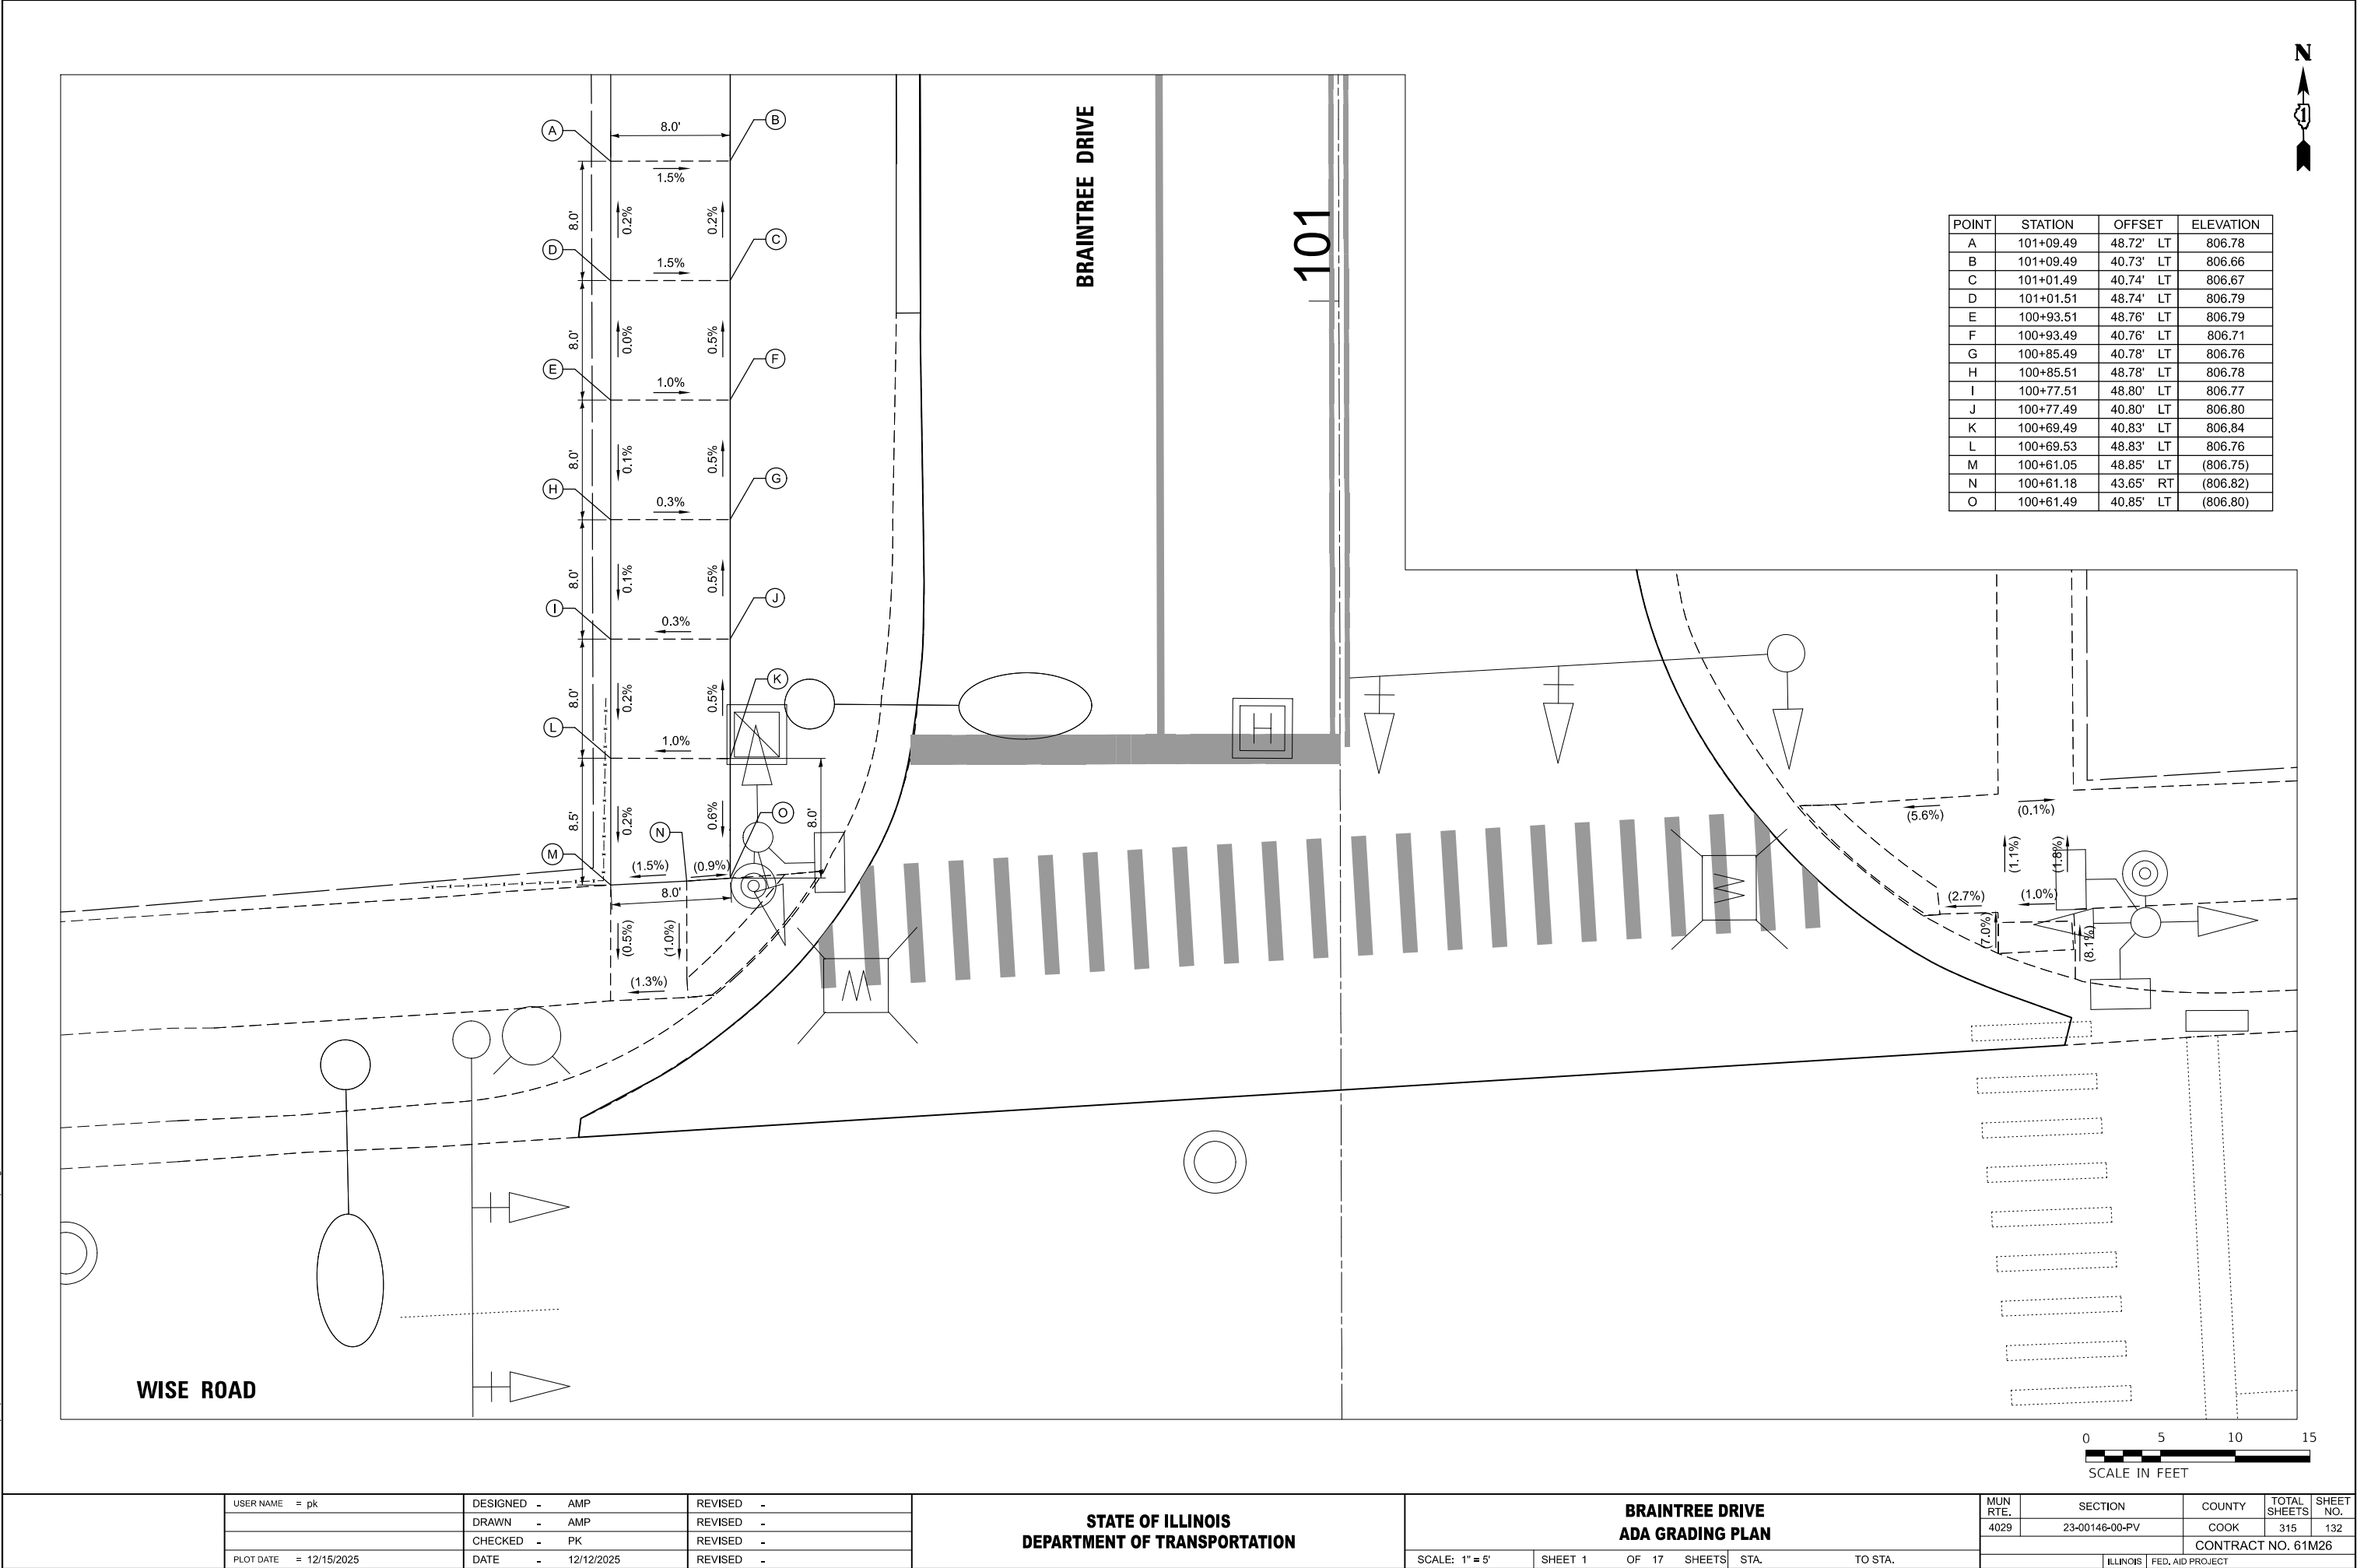

POINT	STATION	OFFSET	ELEVATION
A	101+09.49	48.72' LT	806.78
B	101+09.49	40.73' LT	806.66
C	101+01.49	40.74' LT	806.67
D	101+01.51	48.74' LT	806.79
E	100+93.51	48.76' LT	806.79
F	100+93.49	40.76' LT	806.71
G	100+85.49	40.78' LT	806.76
H	100+85.51	48.78' LT	806.78
I	100+77.51	48.80' LT	806.77
J	100+77.49	40.80' LT	806.80
K	100+69.49	40.83' LT	806.84
L	100+69.53	48.83' LT	806.76
M	100+61.05	48.85' LT	(806.75)
N	100+61.18	43.65' RT	(806.82)
O	100+61.49	40.85' LT	(806.80)



USER NAME = pk	DESIGNED - AMP	REVISED -
	DRAWN - AMP	REVISED -
	CHECKED - PK	REVISED -
	DATE - 12/12/2025	REVISED -
PLOT DATE = 12/15/2025	DATE - 12/12/2025	REVISED -


STATE OF ILLINOIS
DEPARTMENT OF TRANSPORTATION

BRAINTREE DRIVE
ADA GRADING PLAN

SCALE: 1" = 5' SHEET 1 OF 17 SHEETS STA. TO STA.

MUN RTE.	SECTION	COUNTY	TOTAL SHEETS	SHEET NO.
4029	23-00146-00-PV	COOK	315	132
CONTRACT NO. 61M26				
ILLINOIS FED. AID PROJECT				

MODEL: ADA-2 [Steel]
FILE NAME: c:\bns\citytech-pw\patro.kravets\dd1405673993 ADA Curb Ramps.dgn

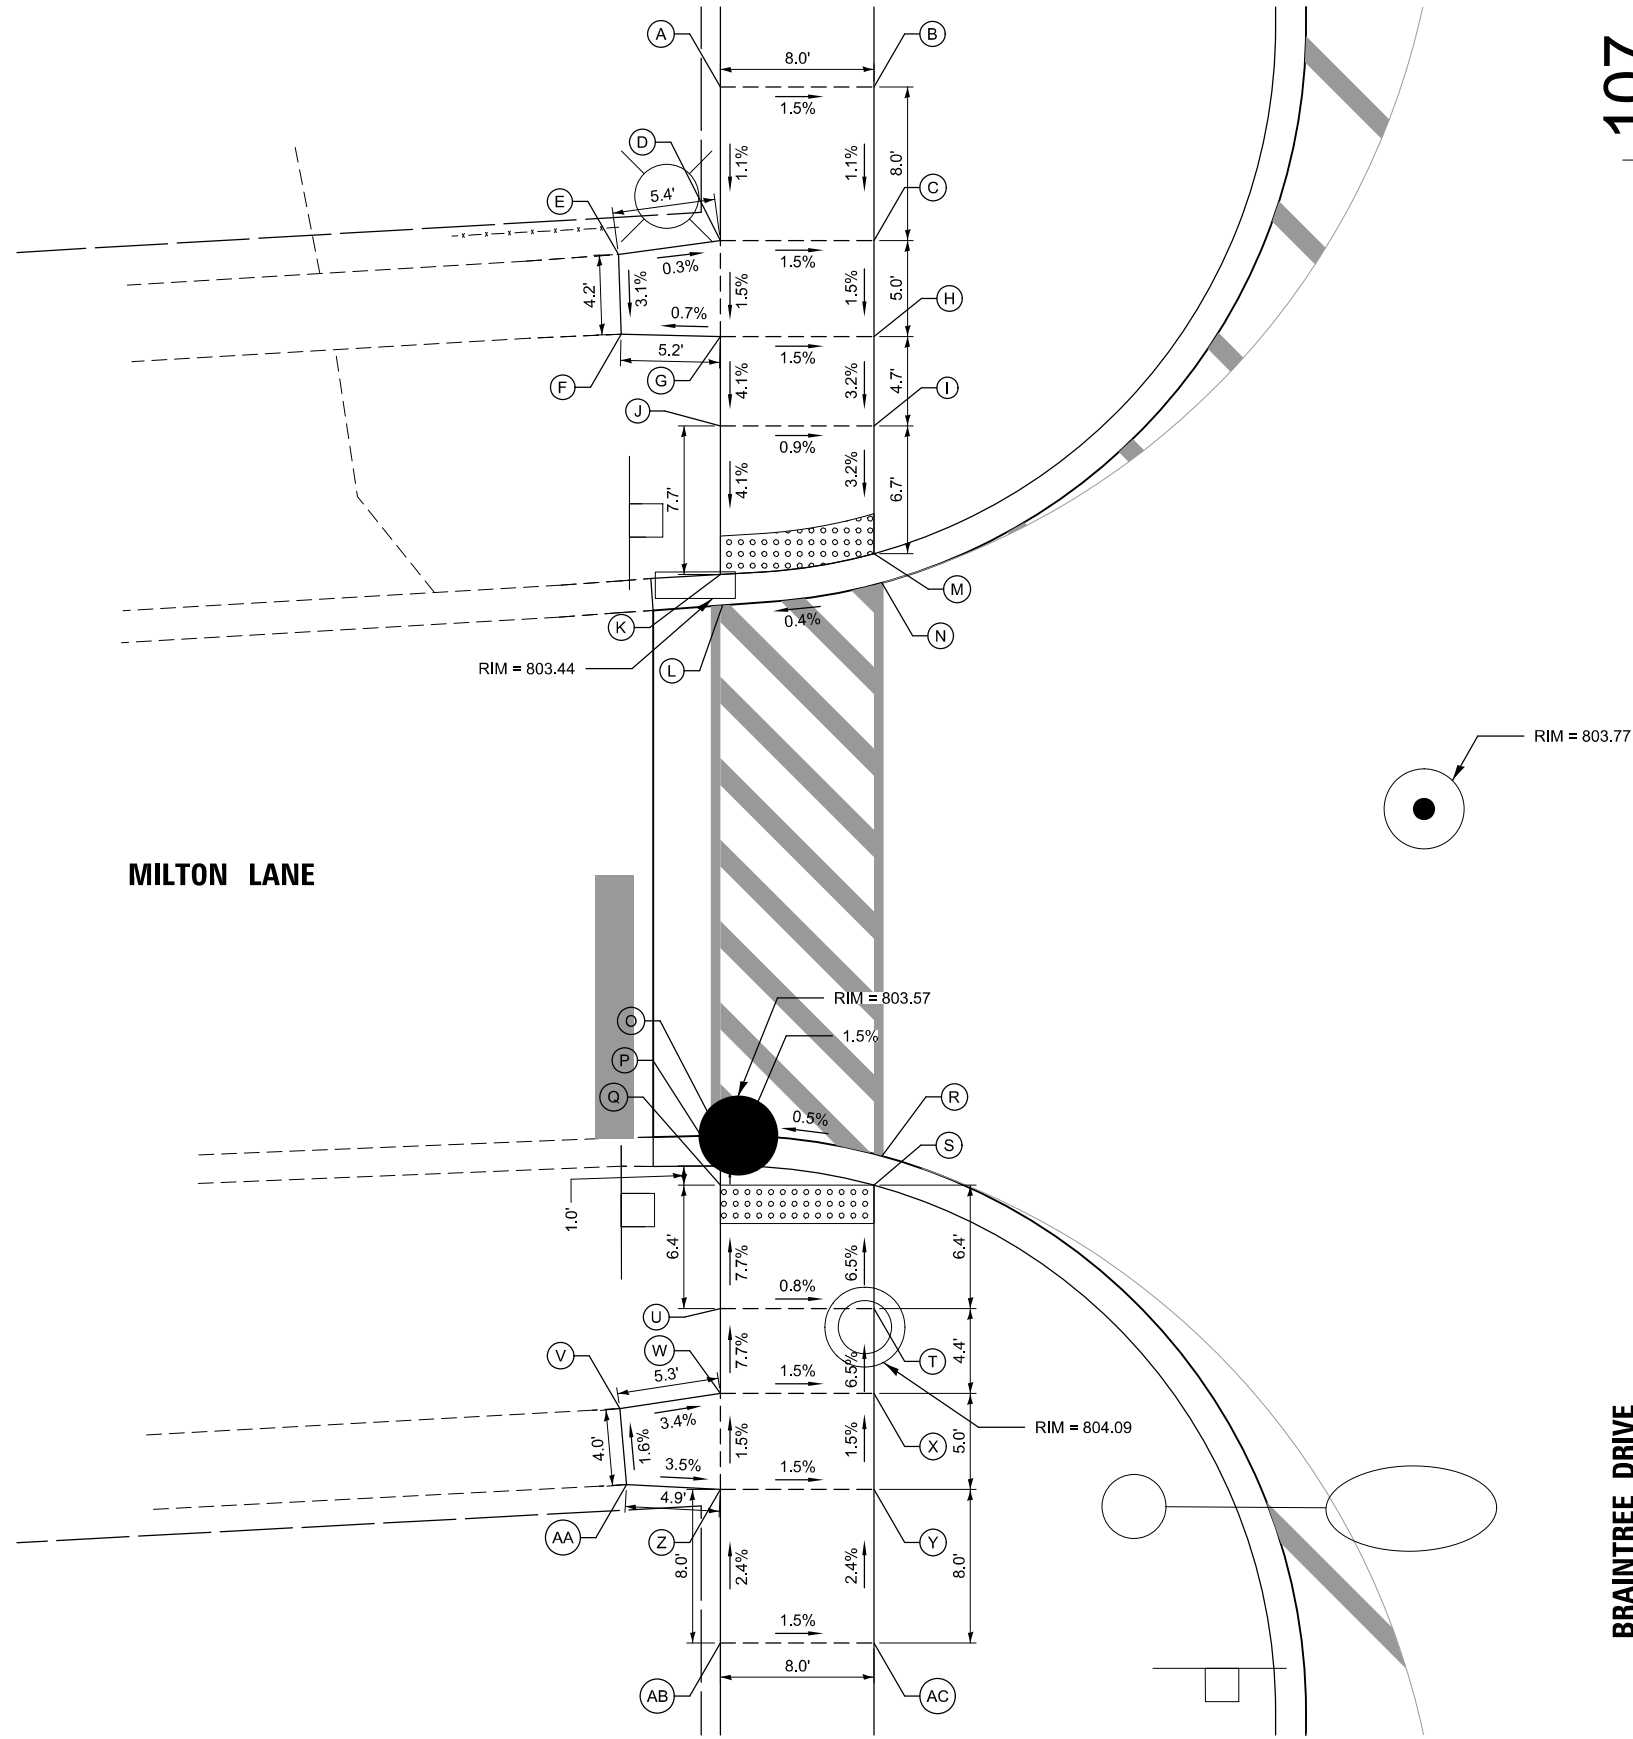

POINT	STATION	OFFSET	ELEVATION
A	107+03.81	49.00' LT	804.12
B	107+03.81	41.00' LT	804.00
C	106+95.81	41.00' LT	803.91
D	106+95.81	49.00' LT	804.03
E	106+95.08	54.31' LT	(804.05)
F	106+90.92	54.17' LT	(803.92)
G	106+90.82	49.00' LT	803.96
H	106+90.81	41.00' LT	803.84
I	106+86.15	41.00' LT	803.69
J	106+86.15	49.00' LT	803.75
K	106+78.41	49.00' LT	803.44
L	106+76.80	49.03' LT	803.45
M	106+79.50	41.00' LT	803.47
N	106+77.98	40.58' LT	803.48
O	106+49.19	49.03' LT	803.58
P	106+47.61	49.00' LT	803.57
Q	106+46.61	49.00' LT	803.59
R	106+48.13	40.58' LT	803.61
S	106+46.61	41.00' LT	803.60
T	106+40.18	41.00' LT	804.02
U	106+40.18	49.00' LT	804.09
V	106+34.96	54.23' LT	(804.61)
W	106+35.76	49.00' LT	804.43
X	106+35.76	41.00' LT	804.31
Y	106+30.76	41.00' LT	804.38
Z	106+30.76	49.00' LT	804.50
AA	106+31.01	53.89' LT	(804.67)
AB	106+22.76	49.00' LT	804.70
AC	106+22.76	41.00' LT	804.58



PLOT DATE = 12/15/2025	USER NAME = pk	DESIGNED - AMP	REVISED -
		DRAWN - AMP	REVISED -
		CHECKED - PK	REVISED -
	DATE - 12/12/2025	REVISED -	


STATE OF ILLINOIS
DEPARTMENT OF TRANSPORTATION

BRAINTREE DRIVE
ADA GRADING PLAN

SCALE: 1" = 5' SHEET 2 OF 17 SHEETS STA. TO STA.

MUN RTE.	SECTION	COUNTY	TOTAL SHEETS	SHEET NO.
4029	23-00146-00-PV	COOK	315	133
CONTRACT NO. 61M26				
ILLINOIS FED. AID PROJECT				

 BRAINTREE DRIVE



POINT	STATION	OFFSET	ELEVATION
A	126+88.23	48.00' LT	799.68
B	126+88.23	40.00' LT	799.56
C	126+81.07	40.00' LT	799.56
D	126+81.07	48.00' LT	799.68
E	126+80.12	54.03' LT	(799.79)
F	126+76.73	53.64' LT	(799.76)
G	126+76.68	48.00' LT	799.62
H	126+76.68	40.00' LT	799.51
I	126+72.53	40.00' LT	799.43
J	126+72.53	48.00' LT	799.55
K	126+65.65	48.00' LT	799.42
L	126+66.58	40.00' LT	799.26
M	126+65.22	39.58' LT	799.26
N	126+64.22	47.89' LT	799.43
O	126+40.37	47.95' LT	799.07
P	126+39.43	39.58' LT	799.03
Q	126+38.06	40.00' LT	799.02
R	126+38.98	48.00' LT	799.06
S	126+32.58	48.00' LT	799.36
T	126+32.58	40.00' LT	799.26
U	126+28.88	40.00' LT	799.42
V	126+28.88	48.00' LT	799.54
W	126+28.98	53.00' LT	799.60
X	126+29.07	58.00' LT	799.66
Y	126+28.76	63.14' LT	(799.72)
Z	126+25.32	63.05' LT	(799.79)
AA	126+24.79	58.14' LT	799.73
AB	126+24.65	53.14' LT	799.67
AC	126+24.50	48.00' LT	799.61
AD	126+24.50	40.00' LT	799.49
AE	126+17.33	40.00' LT	799.81
AF	126+17.33	48.00' LT	799.69



MUN. RTE.	SECTION	COUNTY	TOTAL SHEETS	SHEET NO.
4029	23-00146-00-PV	COOK	315	136
CONTRACT NO. 61M26				
ILLINOIS FED. AID PROJECT				


BRAINTREE DRIVE ADA GRADING PLAN			
SCALE: 1" = 5'	SHEET 5	OF 17 SHEETS	STA. TO STA.

STATE OF ILLINOIS DEPARTMENT OF TRANSPORTATION			
DESIGNED - AMP	REVISED -		
DRAWN - AMP	REVISED -		
CHECKED - PK	REVISED -		
DATE - 12/12/2025	REVISED -		

USER NAME = pk			
PLOT DATE = 12/15/2025			

BRAINTREE DRIVE

RADCLIFFE LANE

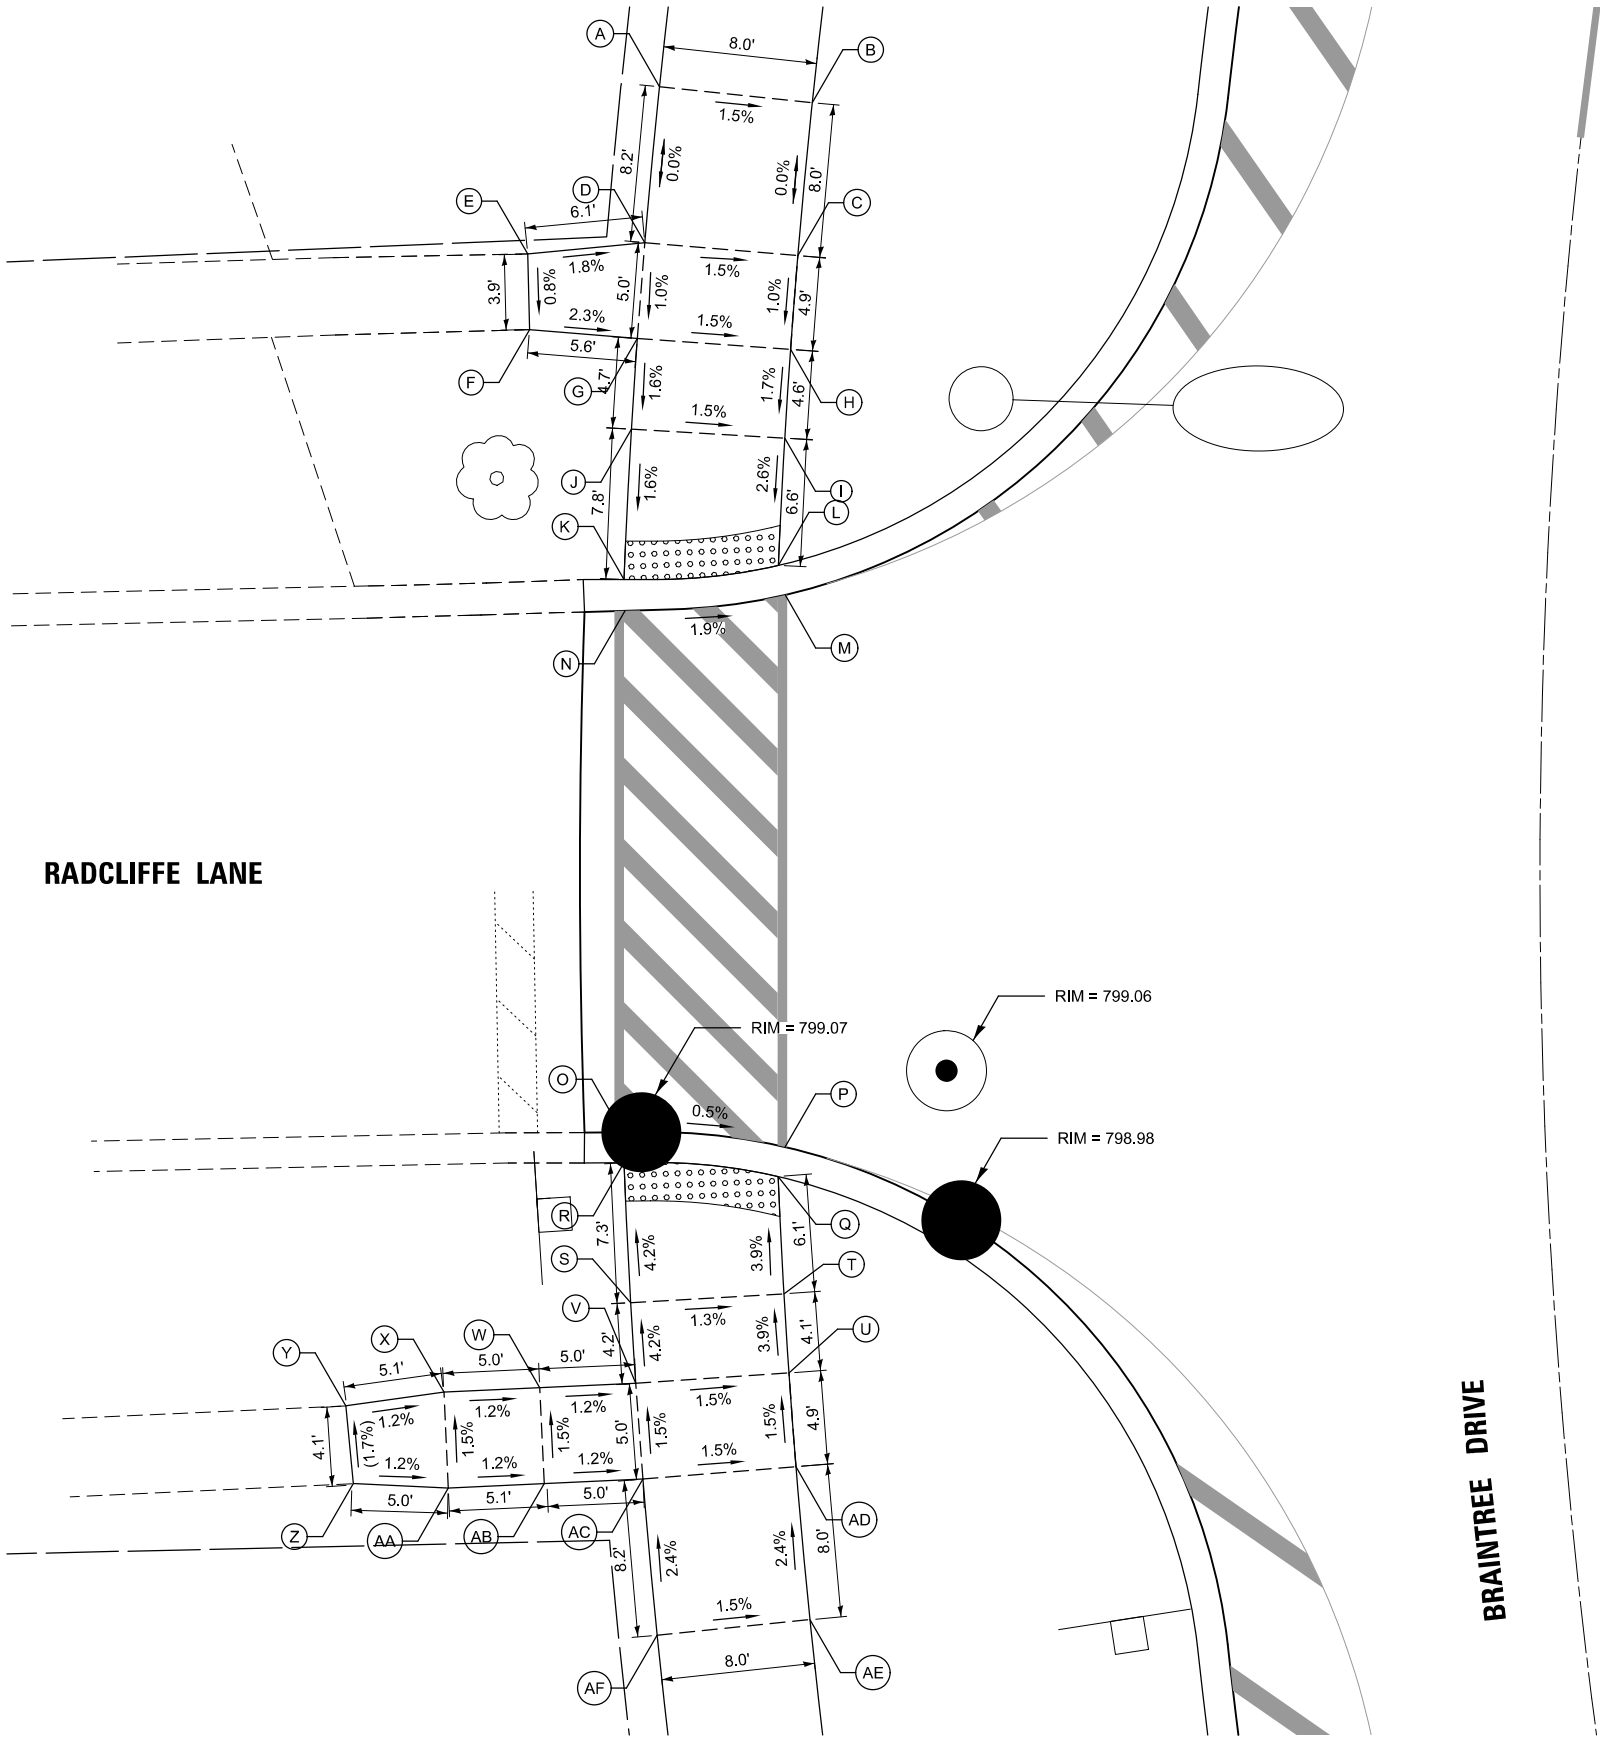

MODEL: ADA-5 [Sheet]
FILE NAME: c:\bns\sk\tech-pw\patro.kravets\dd1405673993 ADA Curb Ramps.dgn




MUN RTE.	SECTION	COUNTY	TOTAL SHEETS	SHEET NO.
4029	23-00146-00-PV	COOK	315	137
		CONTRACT NO. 61M26		
ILLINOIS		FED. AID PROJECT		

MODEL: ADA-7 [Sheet]
FILE NAME: c:\bns\sk\tech-pw\patro.kravets\dd14056713993 ADA Curb Ramps.dgn

132

BRAINTREE DRIVE

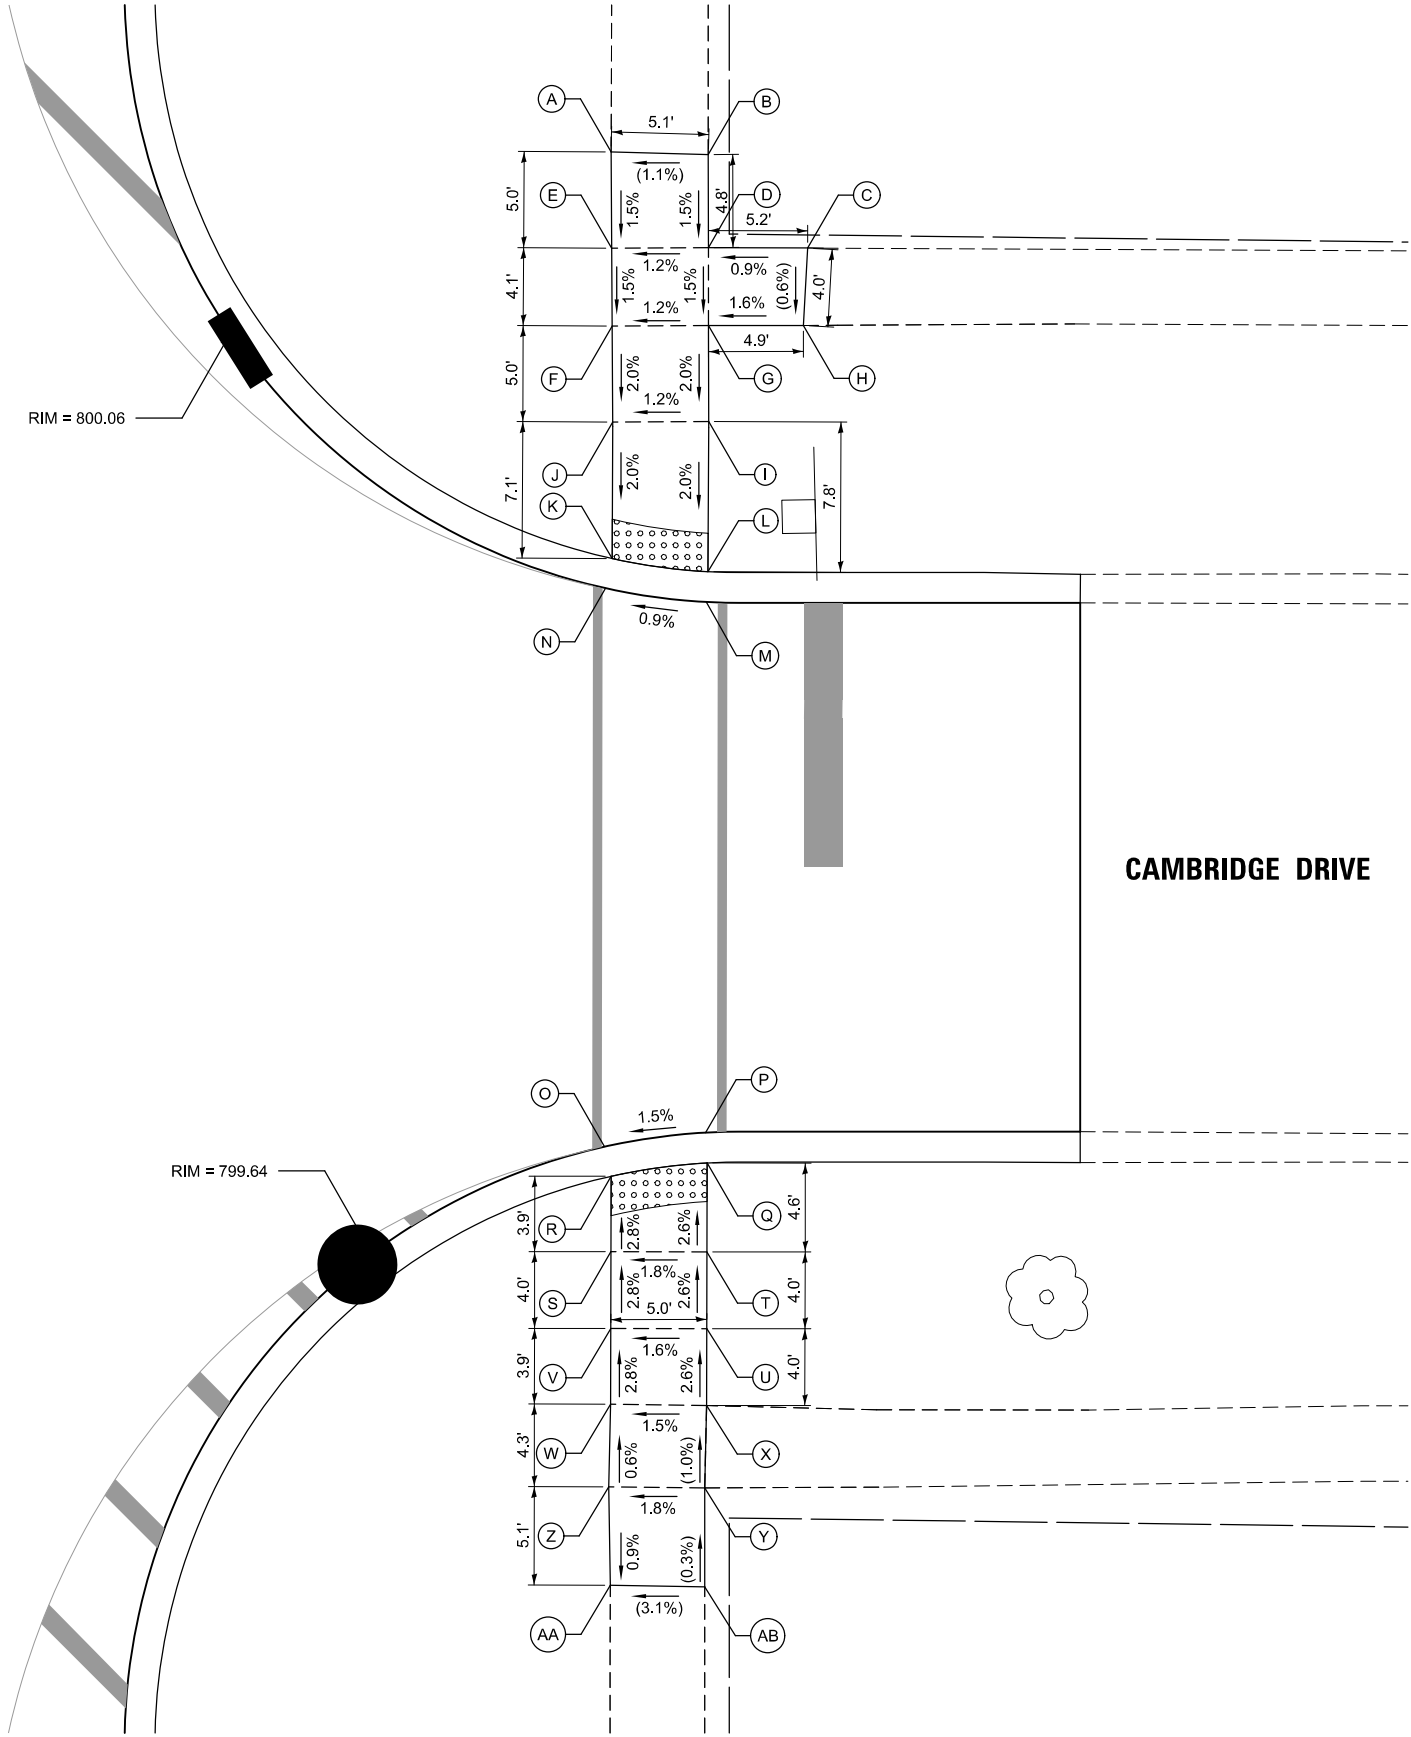

POINT	STATION	OFFSET	ELEVATION
A	132+49.63	43.84' RT	(800.64)
B	132+49.50	48.90' RT	(800.70)
C	132+44.63	54.08' RT	(800.67)
D	132+44.65	48.91' RT	800.62
E	132+44.62	43.87' RT	800.57
F	132+40.56	43.90' RT	800.51
G	132+40.59	48.92' RT	800.56
H	132+40.60	53.86' RT	(800.64)
I	132+35.59	48.93' RT	800.46
J	132+35.56	43.92' RT	800.41
K	132+28.45	43.89' RT	800.26
L	132+27.77	48.89' RT	800.31
M	132+26.19	48.80' RT	800.32
N	132+26.91	43.55' RT	800.27
O	131+97.82	43.49' RT	799.86
P	131+98.55	48.75' RT	799.94
Q	131+96.97	48.84' RT	799.93
R	131+96.28	43.84' RT	799.85
S	131+92.35	43.83' RT	799.96
T	131+92.35	48.83' RT	800.05
U	131+88.35	48.83' RT	800.15
V	131+88.35	43.83' RT	800.07
W	131+84.41	43.82' RT	800.18
X	131+84.35	48.82' RT	(800.26)
Y	131+80.05	48.71' RT	(800.30)
Z	131+80.11	43.71' RT	800.21
AA	131+74.99	43.81' RT	(800.16)
AB	131+74.89	48.72' RT	(800.31)



USER NAME = pk	DESIGNED - AMP	REVISED -
	DRAWN - AMP	REVISED -
	CHECKED - PK	REVISED -
PLOT DATE = 12/15/2025	DATE - 12/12/2025	REVISED -


STATE OF ILLINOIS
DEPARTMENT OF TRANSPORTATION

BRAINTREE DRIVE
ADA GRADING PLAN

SCALE: 1" = 5' SHEET 7 OF 17 SHEETS STA. TO STA.

MUN. RTE.	SECTION	COUNTY	TOTAL SHEETS	SHEET NO.
4029	23-00146-00-PV	COOK	315	138
CONTRACT NO. 61M26				
ILLINOIS FED. AID PROJECT				

MODEL: ADA-8 [Sheet]
FILE NAME: c:\bns\citytech-pw\patro.kravets\dd1405673983 ADA Curb Ramps.dgn

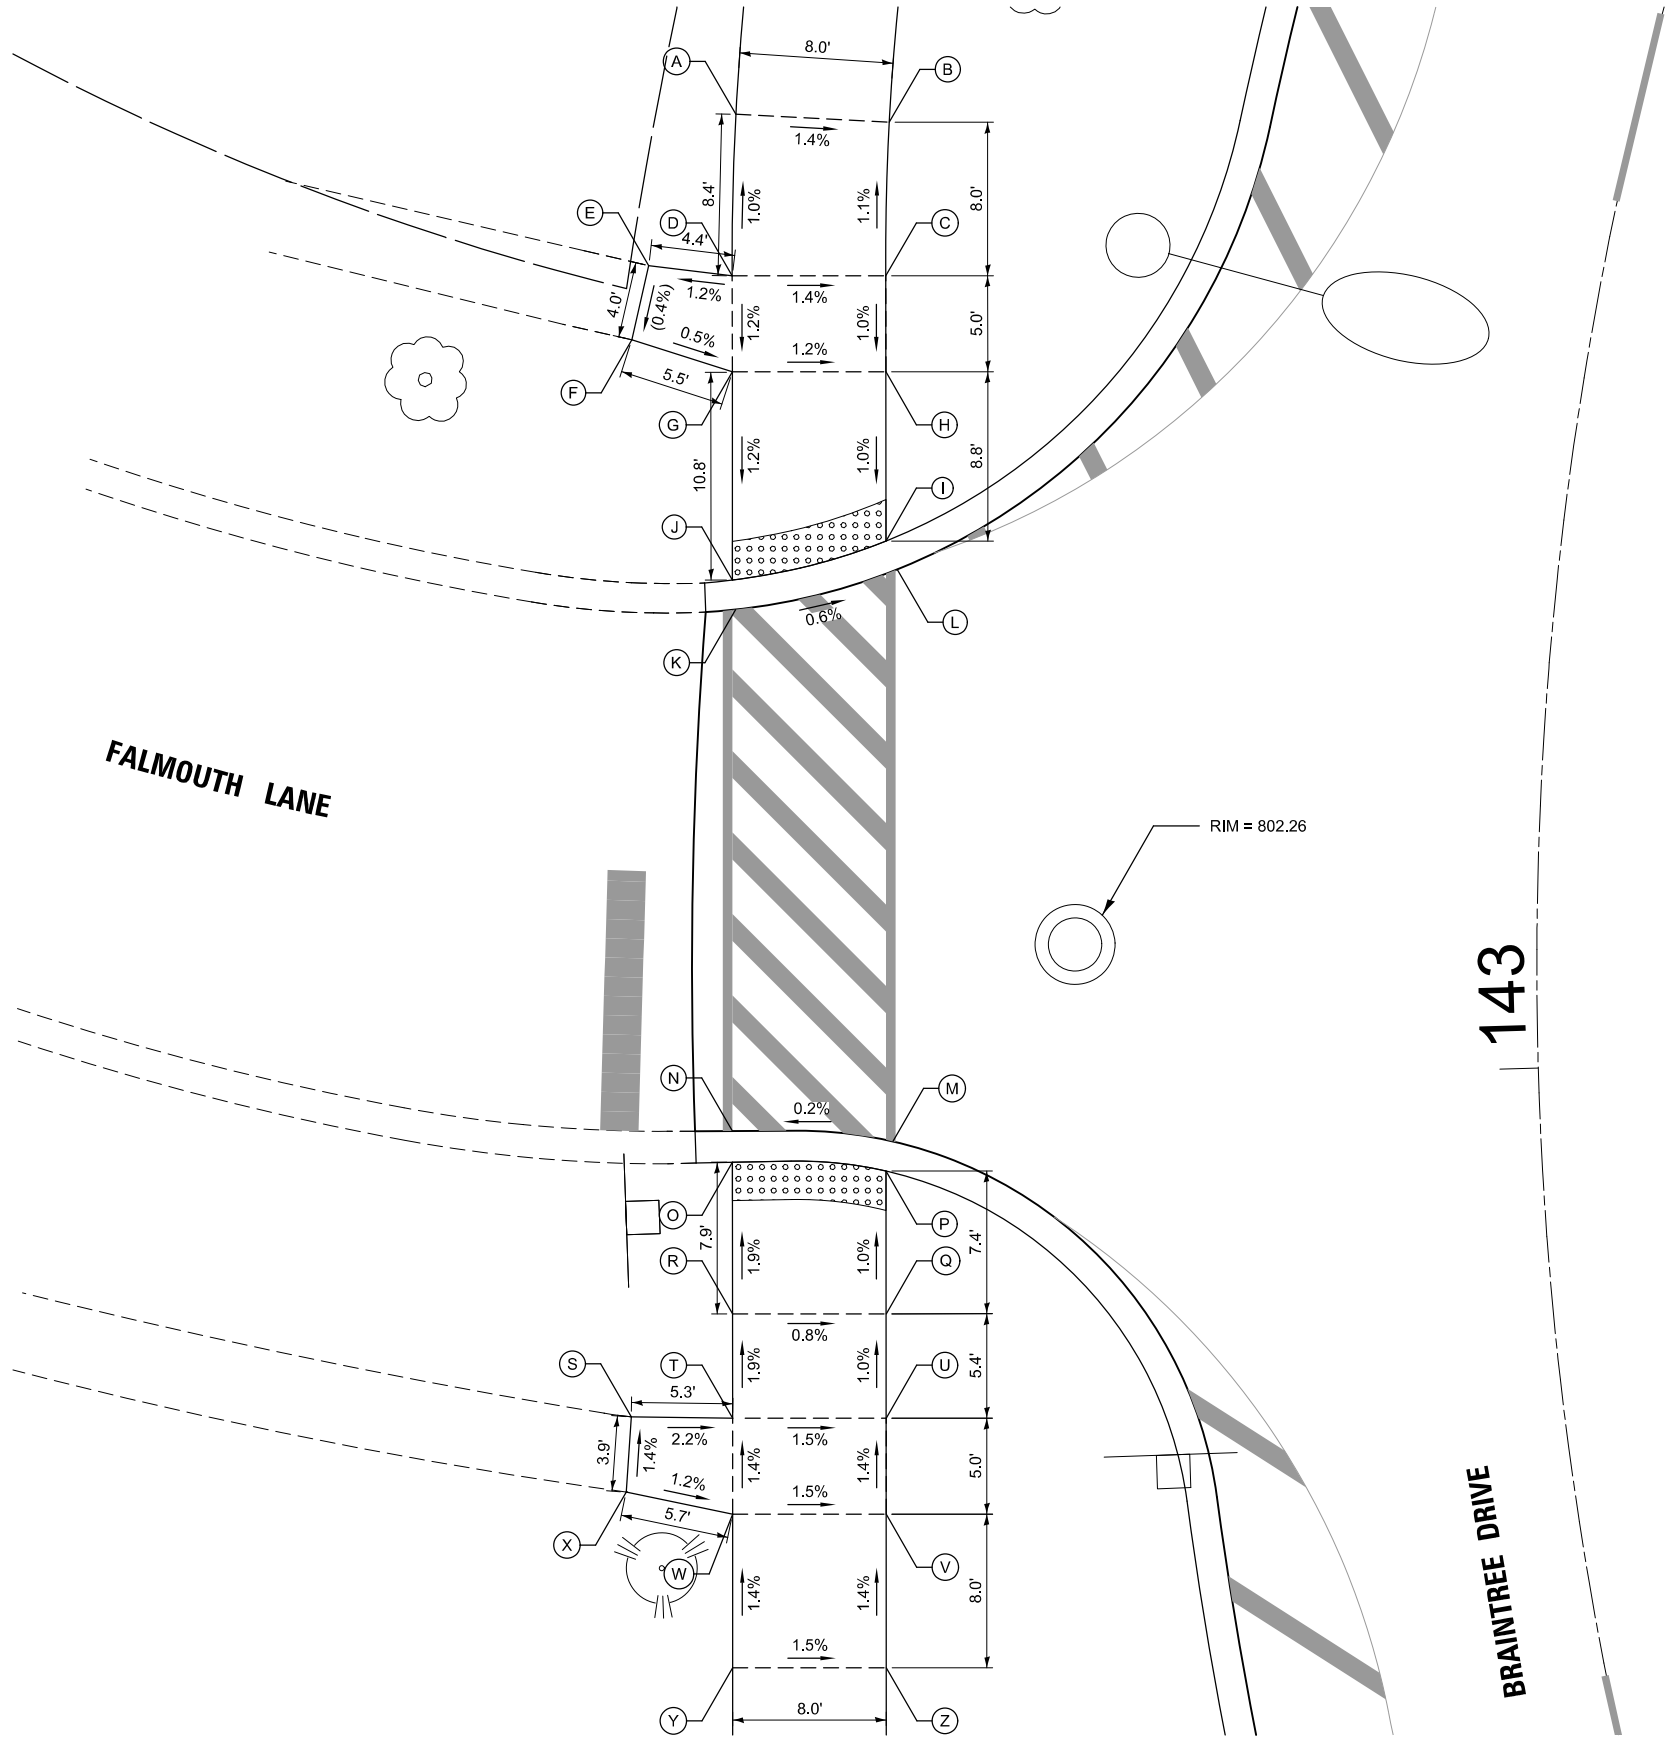

POINT	STATION	OFFSET	ELEVATION
A	143+41.31	45.89' LT	802.20
B	143+42.21	37.97' LT	802.09
C	143+35.60	36.75' LT	802.18
D	143+34.57	44.65' LT	802.29
E	143+34.46	49.03' LT	(802.24)
F	143+31.33	49.35' LT	(802.25)
G	143+30.56	43.94' LT	802.23
H	143+31.44	36.01' LT	802.13
I	143+24.06	34.98' LT	802.04
J	143+21.77	42.76' LT	802.09
K	143+20.53	42.47' LT	802.10
L	143+22.87	34.26' LT	802.05
M	142+97.56	33.73' LT	802.29
N	142+98.28	42.06' LT	802.28
O	142+96.95	42.12' LT	802.27
P	142+96.26	34.15' LT	802.28
Q	142+89.97	34.62' LT	802.36
R	142+90.50	42.60' LT	802.42
S	142+86.56	48.32' LT	(802.65)
T	142+86.08	43.08' LT	802.53
U	142+85.40	35.13' LT	802.41
V	142+81.21	35.70' LT	802.48
W	142+82.03	43.64' LT	802.60
X	142+83.48	49.00' LT	(802.67)
Y	142+75.59	44.75' LT	802.71
Z	142+74.55	36.85' LT	802.59



	USER NAME = pk	DESIGNED - AMP	REVISED -
		DRAWN - AMP	REVISED -
		CHECKED - PK	REVISED -
	PLOT DATE = 12/15/2025	DATE - 12/12/2025	REVISED -

STATE OF ILLINOIS
DEPARTMENT OF TRANSPORTATION

BRAINTREE DRIVE
ADA GRADING PLAN

SCALE: 1" = 5' SHEET 8 OF 17 SHEETS STA. TO STA.

MUN RTE.	SECTION	COUNTY	TOTAL SHEETS	SHEET NO.
4029	23-00146-00-PV	COOK	315	139
CONTRACT NO. 61M26				
		ILLINOIS	FED. AID PROJECT	



CAMBRIDGE DRIVE

BRAINTREE DRIVE
147

POINT	STATION	OFFSET	ELEVATION
A	147+39.92	48.56' LT	806.74
B	147+39.88	40.56' LT	806.62
C	147+39.86	35.94' LT	806.40
D	147+39.83	31.32' LT	806.18
E	147+39.81	26.70' LT	805.97
F	147+39.77	20.08' LT	805.66
G	147+39.77	18.50' LT	805.67
H	147+34.57	18.50' LT	805.57
I	147+34.57	20.08' LT	805.56
J	147+34.54	26.70' LT	805.89
K	147+34.52	31.32' LT	806.11
L	147+34.50	35.94' LT	806.33
M	147+34.48	40.59' LT	806.54
N	147+34.52	48.59' LT	806.66
O	147+26.58	28.08' RT	805.10
P	147+25.55	29.23' RT	805.09
Q	147+23.88	35.66' RT	805.21
R	147+22.64	40.52' RT	805.30
S	147+21.44	45.31' RT	805.38
T	147+19.84	51.84' RT	805.50
U	147+15.19	55.64' RT	805.61
V	147+11.60	58.65' RT	805.70
W	147+08.04	61.69' RT	805.79
X	147+10.69	66.45' RT	(806.01)
Y	147+06.97	68.79' RT	(806.05)
Z	147+04.49	64.66' RT	805.87
AA	147+01.89	61.11' RT	805.80
AB	146+98.94	57.77' RT	(805.62)
AC	147+01.88	54.04' RT	(805.60)
AD	147+05.24	57.78' RT	805.72
AE	147+08.86	54.68' RT	805.62
AF	147+12.47	51.65' RT	805.53
AG	147+15.83	48.87' RT	805.44
AH	147+16.99	44.03' RT	805.34
AI	147+18.16	39.19' RT	805.25
AJ	147+19.35	34.36' RT	805.15
AK	147+21.52	25.82' RT	804.98
AL	147+22.36	24.51' RT	804.99



STATE OF ILLINOIS
DEPARTMENT OF TRANSPORTATION


BRAINTREE DRIVE
ADA GRADING PLAN

SCALE: 1" = 5' SHEET 9 OF 17 SHEETS STA. TO STA.

MUN RTE.	SECTION	COUNTY	TOTAL SHEETS	SHEET NO.
4029	23-00146-00-PV	COOK	315	140
CONTRACT NO. 61M26				
ILLINOIS FED. AID PROJECT				

USER NAME = pk	DESIGNED - AMP	REVISED -
	DRAWN - AMP	REVISED -
	CHECKED - PK	REVISED -
DATE = 12/15/2025	DATE - 12/12/2025	REVISED -

MODEL: ADA-9 [Sheet]
FILE NAME: c:\bns\sk\tech-pw\patro.kravets\dd14056713983 ADA Curb Ramps.dgn

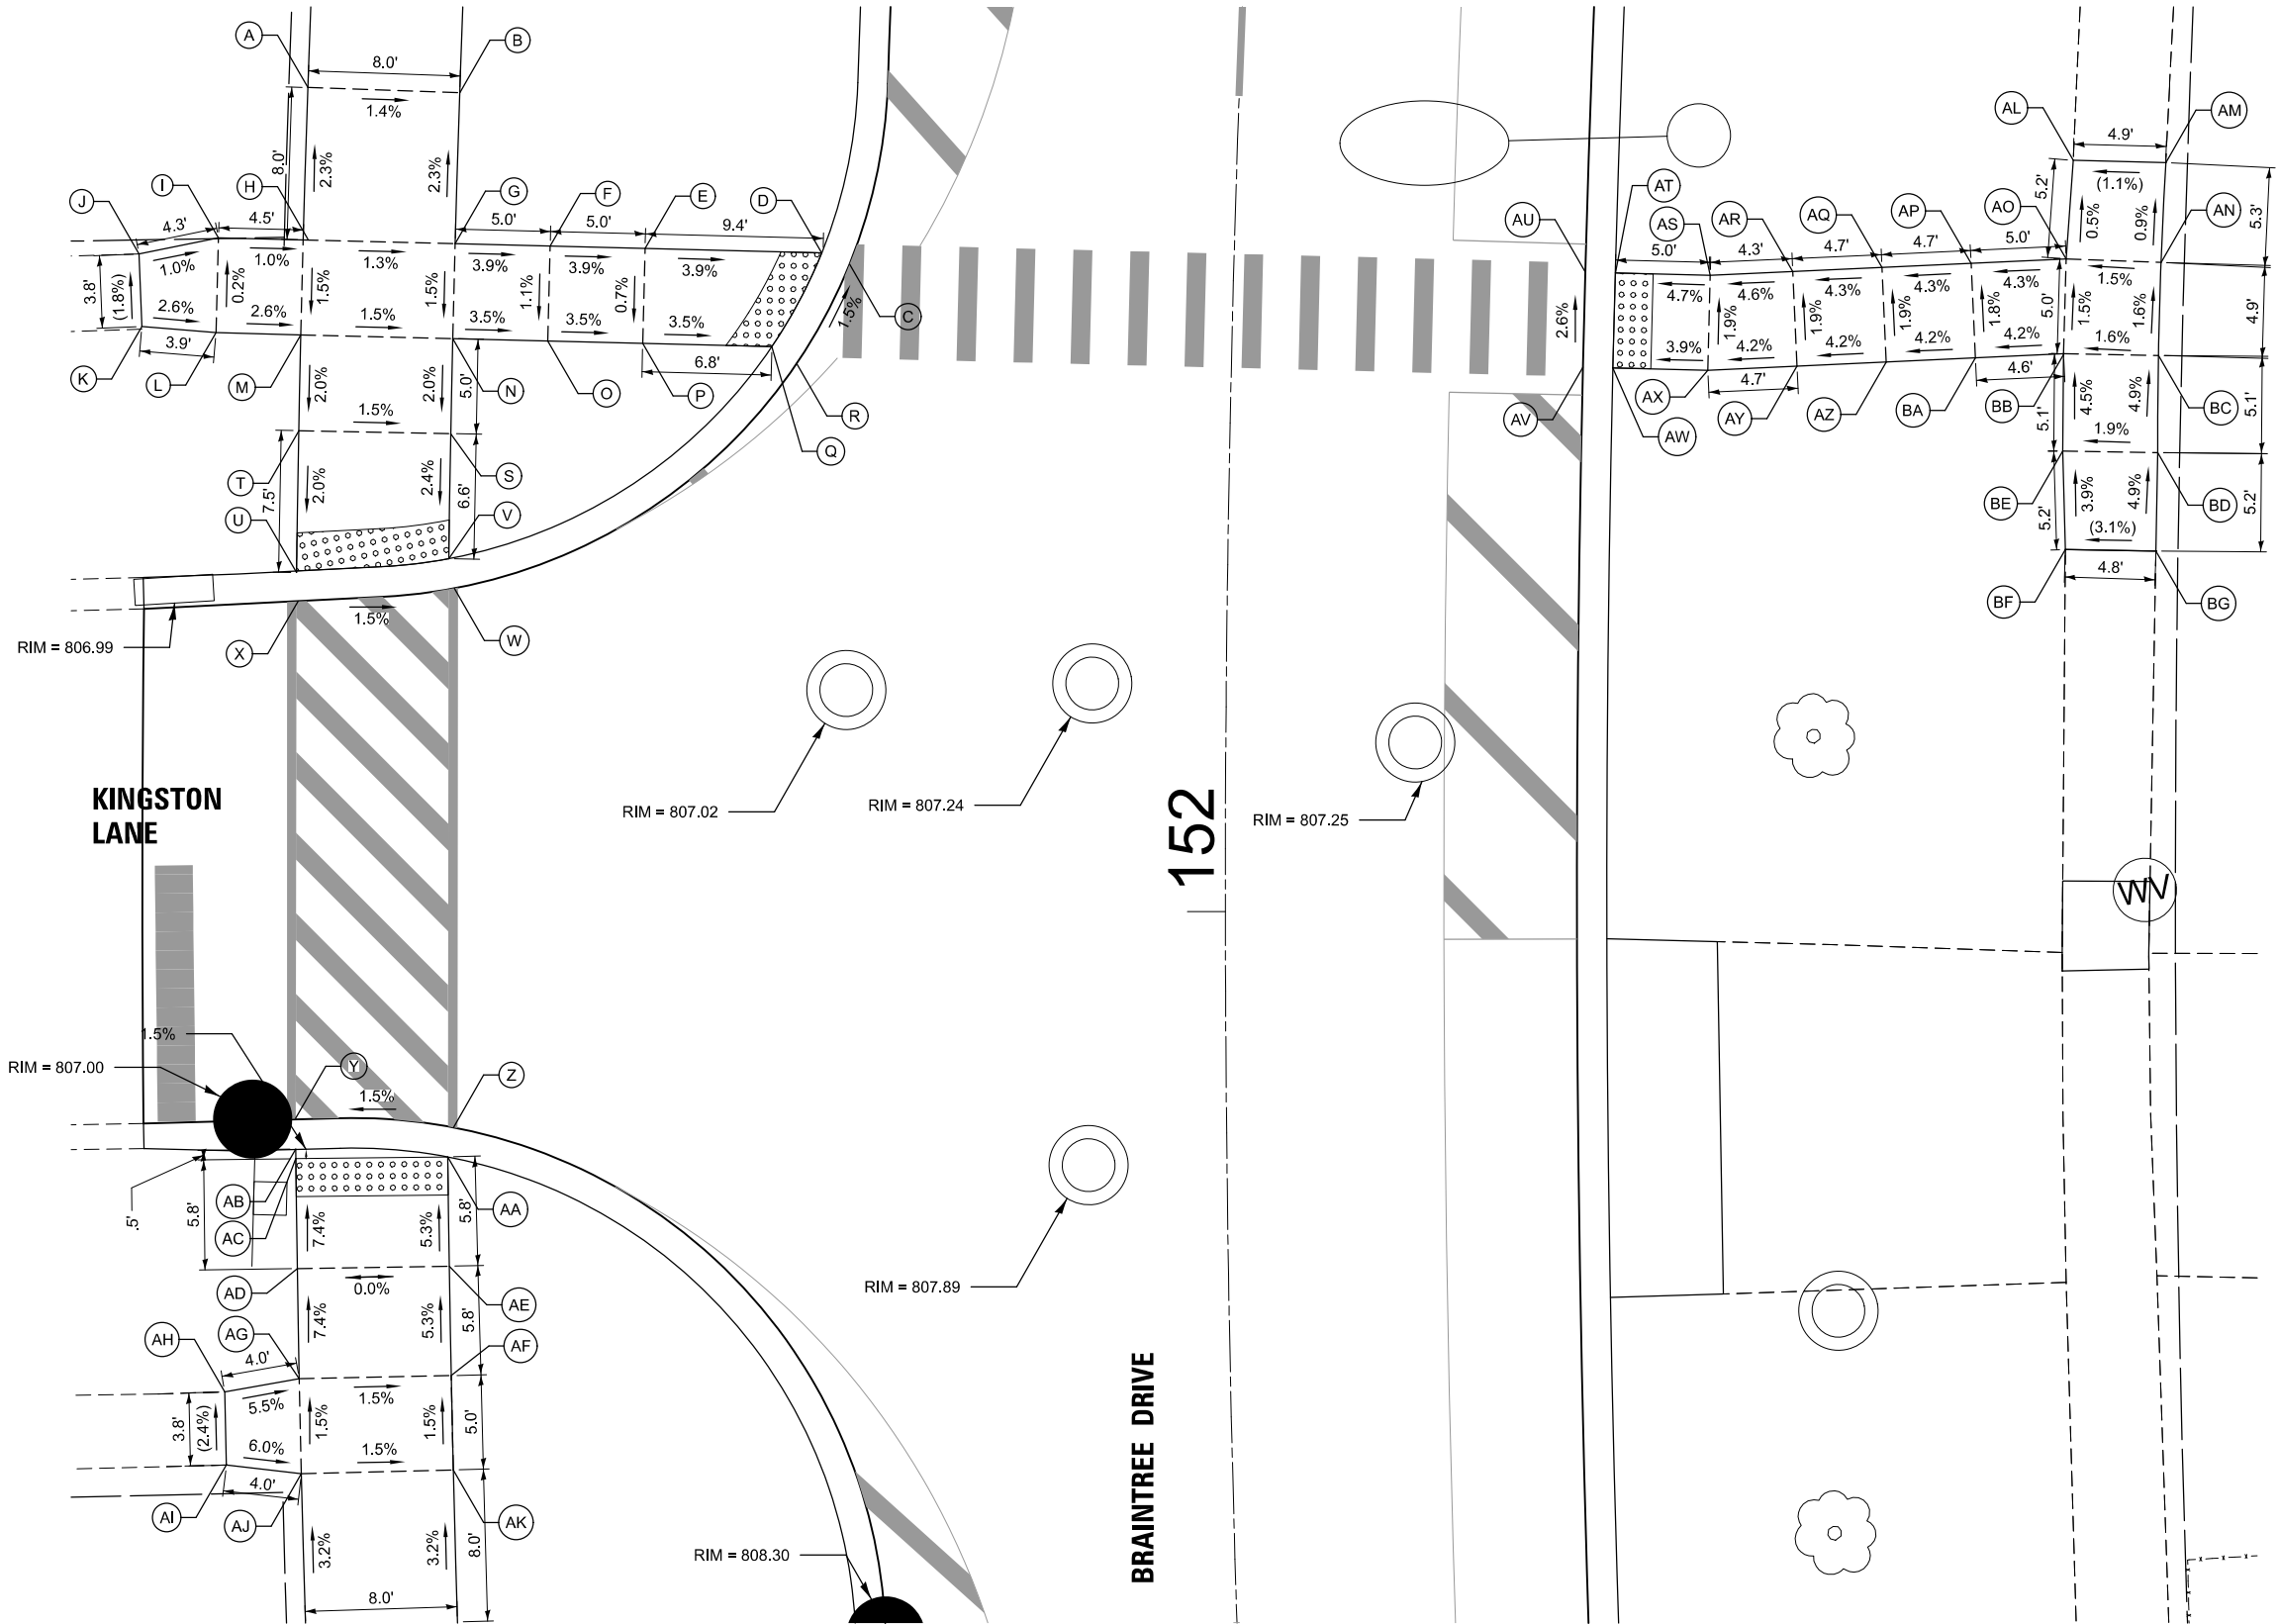

POINT	STATION	OFFSET	ELEVATION
A	152+41.73	49.00' LT	807.01
B	152+41.73	41.00' LT	806.90
C	152+33.54	20.22' LT	806.34
D	152+34.08	21.70' LT	806.33
E	152+34.06	31.00' LT	806.70
F	152+34.05	36.00' LT	806.89
G	152+34.04	41.00' LT	807.19
H	152+34.03	49.00' LT	807.09
I	152+34.02	53.46' LT	807.24
J	152+33.10	57.62' LT	(807.28)
K	152+29.45	57.37' LT	(807.35)
L	152+29.23	53.46' LT	807.25
M	152+29.22	49.00' LT	807.13
N	152+29.20	41.00' LT	807.01
O	152+29.19	36.00' LT	806.84
P	152+29.18	31.00' LT	806.66
Q	152+29.17	24.20' LT	806.42
R	152+28.33	22.87' LT	806.43
S	152+24.37	41.00' LT	806.91
T	152+24.37	49.00' LT	807.03
U	152+17.19	49.00' LT	806.88
V	152+18.00	41.00' LT	806.76
W	152+16.50	40.69' LT	806.77
X	152+15.74	48.90' LT	806.89
Y	151+89.57	49.00' LT	807.03
Z	151+89.04	40.69' LT	807.16
AA	151+87.54	41.00' LT	807.15
AB	151+88.02	49.00' LT	807.03
AC	151+87.54	49.00' LT	807.03
AD	151+81.97	49.00' LT	807.46
AE	151+81.97	41.00' LT	807.46
AF	151+76.41	41.00' LT	807.77
AG	151+76.41	49.00' LT	807.89
AH	151+75.82	52.94' LT	(808.11)
AI	151+72.13	52.94' LT	(808.20)
AJ	151+71.60	49.00' LT	807.96
AK	151+71.60	41.00' LT	807.84
AL	152+40.99	43.99' RT	(807.44)
AM	152+41.03	48.87' RT	(807.49)
AN	152+35.55	48.78' RT	807.54
AO	152+35.60	43.78' RT	807.46
AP	152+35.21	38.78' RT	807.25
AQ	152+34.86	34.10' RT	807.05
AR	152+34.50	29.41' RT	806.85
AS	152+34.18	25.08' RT	806.65
AT	152+34.16	20.08' RT	806.42
AU	152+34.16	18.50' RT	806.42
AV	152+29.08	18.50' RT	806.56
AW	152+29.08	20.08' RT	806.55
AX	152+29.07	25.08' RT	806.75
AY	152+29.40	29.77' RT	807.94
AZ	152+29.74	34.46' RT	807.14
BA	152+30.08	39.14' RT	807.34
BB	152+30.42	43.80' RT	807.54
BC	152+30.45	48.77' RT	807.62
BD	152+25.12	48.84' RT	807.87
BE	152+25.11	43.84' RT	807.77
BF	152+19.73	44.07' RT	(807.97)
BG	152+19.73	48.84' RT	(808.12)



MODEL: ADA-10 (Sheet)
FILE NAME: c:\bms\civil\ch-pw\patro.kravets\dd14056713983 ADA Curb Ramps.dgn

PLOT DATE = 12/11/2025	USER NAME = pk	DESIGNED - AMP	REVISED -
		DRAWN - AMP	REVISED -
		CHECKED - PK	REVISED -
	DATE - 12/12/2025	REVISED -	


STATE OF ILLINOIS
DEPARTMENT OF TRANSPORTATION

BRAINTREE DRIVE
ADA GRADING PLAN

SCALE: 1" = 5' SHEET 10 OF 17 SHEETS STA. TO STA.

MUN RTE.	SECTION	COUNTY	TOTAL SHEETS	SHEET NO.
4029	23-00146-00-PV	COOK	315	141
CONTRACT NO. 61M26				
ILLINOIS FED. AID PROJECT				

WEATHERSFIELD WAY

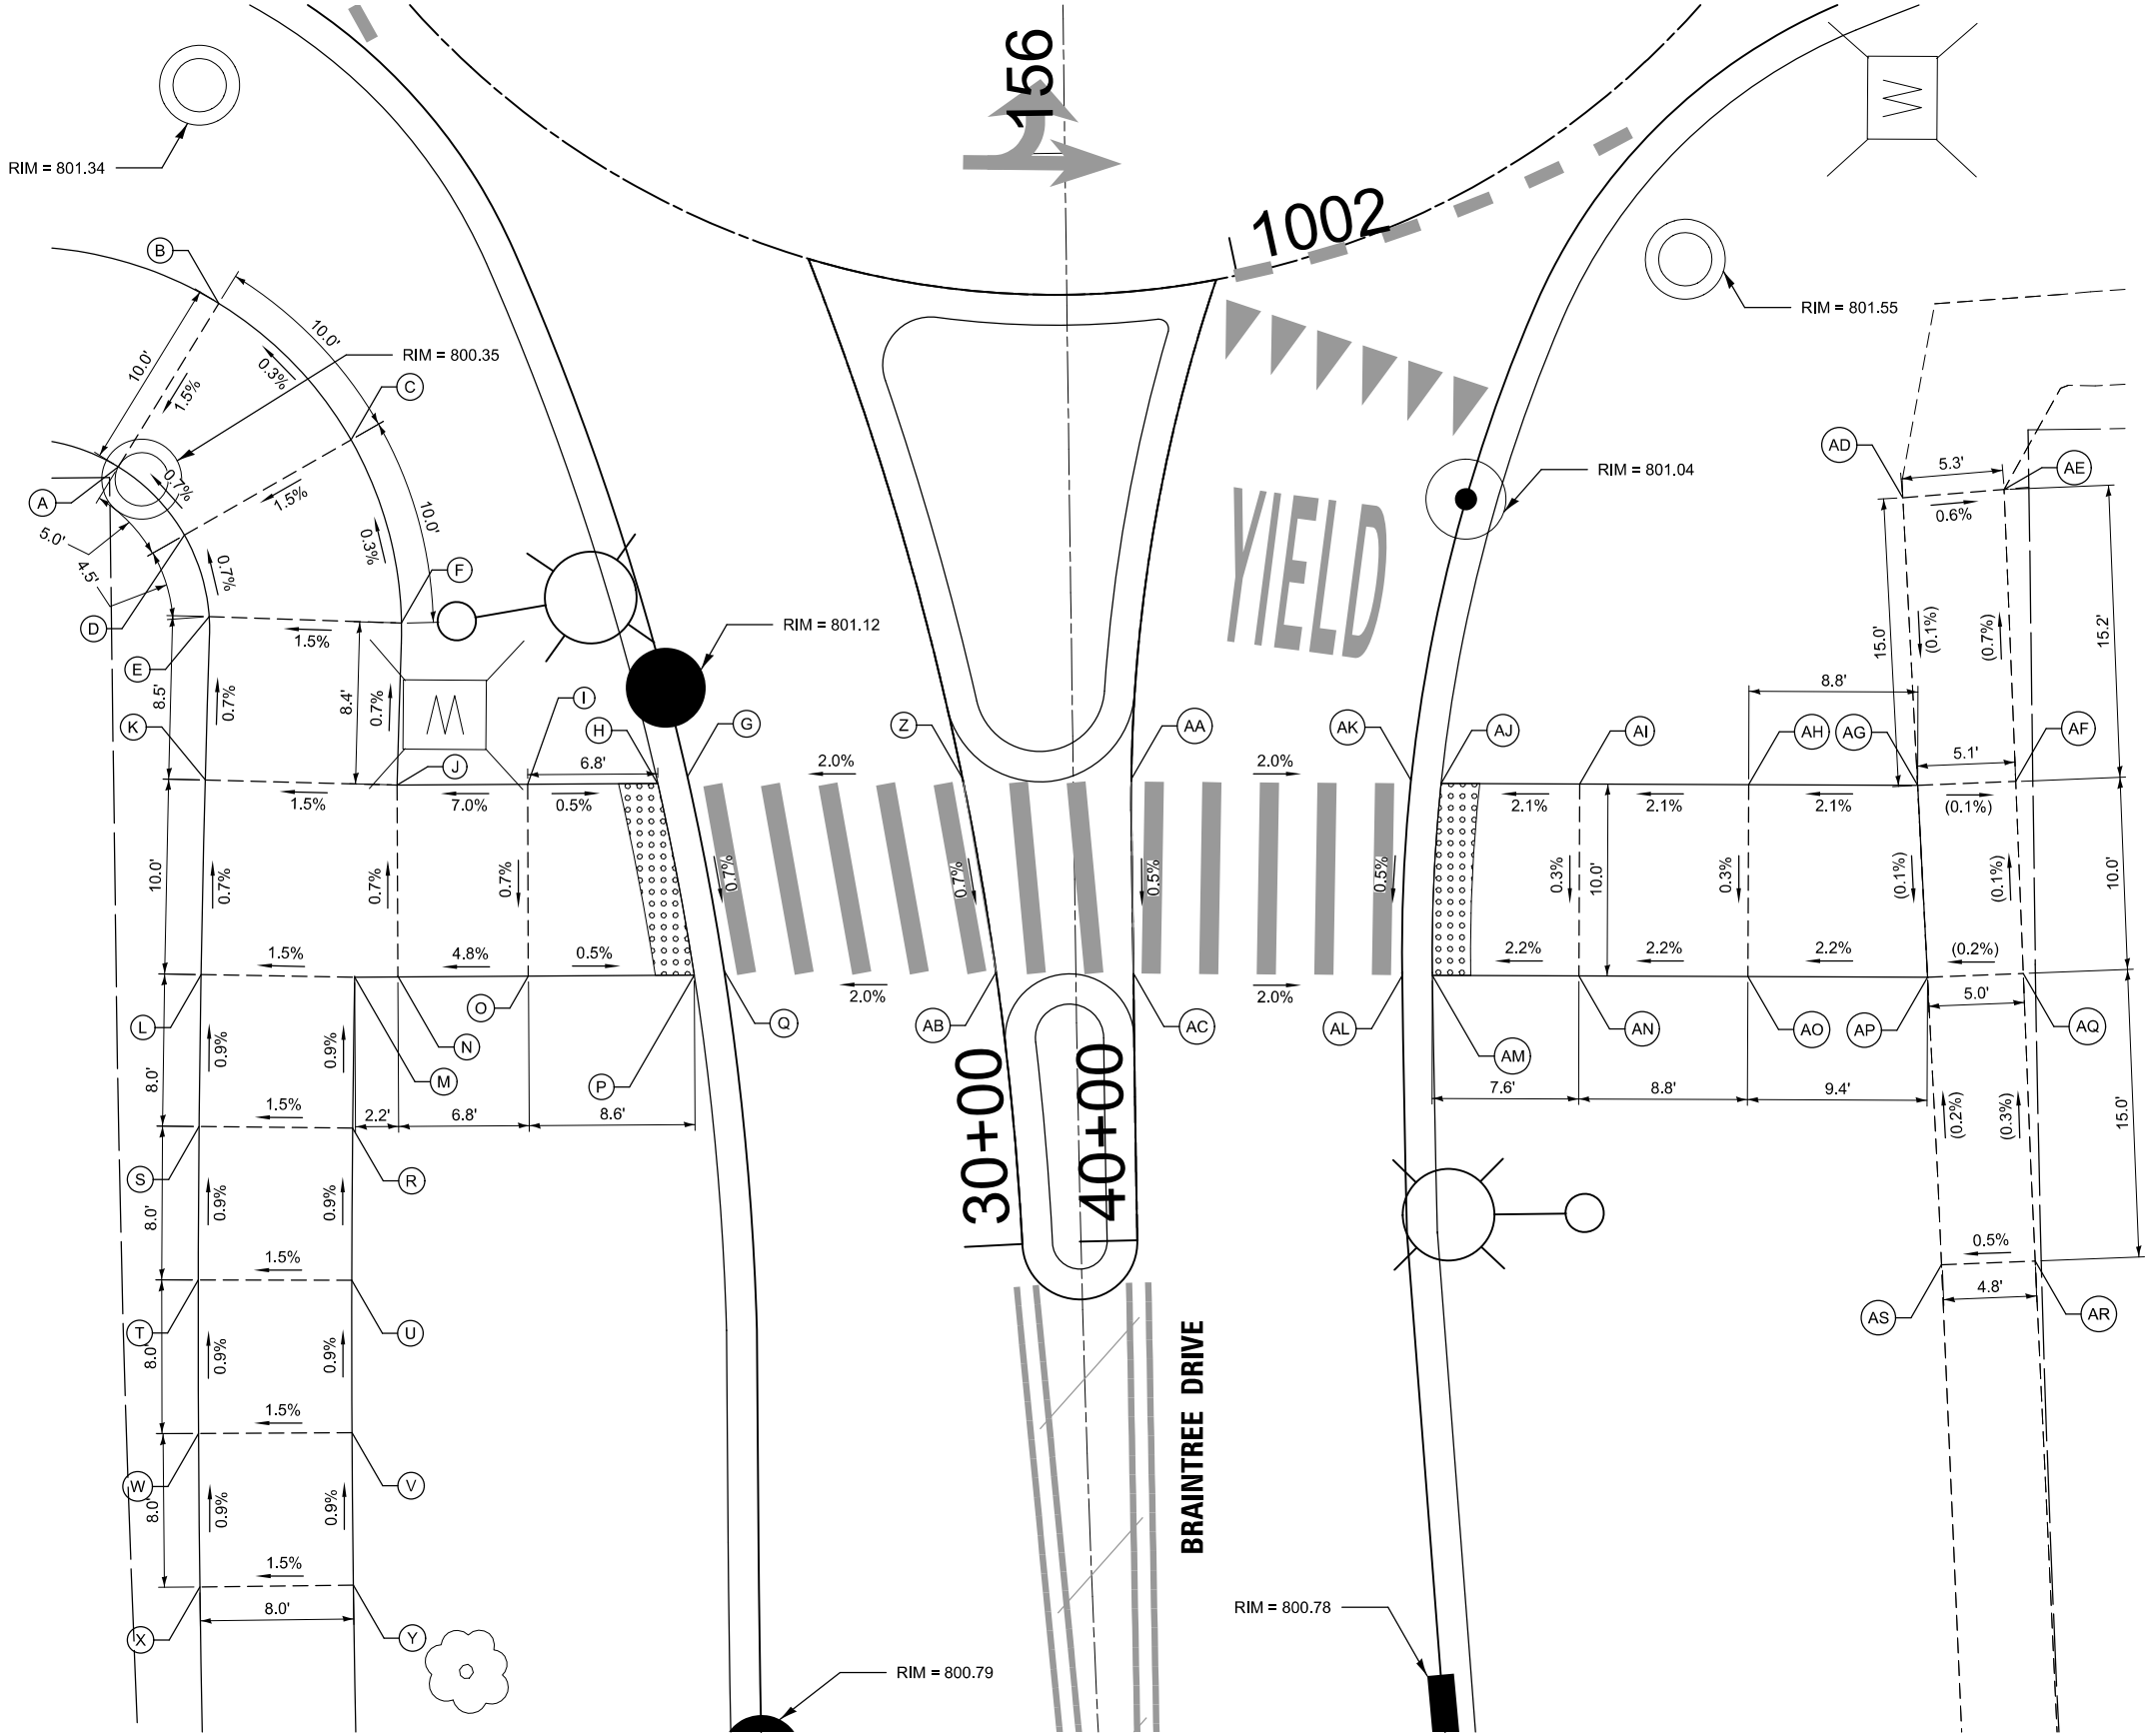

POINT	STATION	OFFSET	ELEVATION
A	155+84.31	49.54' LT	800.34
B	155+92.76	44.19' LT	800.49
C	155+85.56	37.40' LT	800.52
D	155+80.71	46.14' LT	800.38
E	155+76.45	44.91' LT	800.41
F	155+75.98	34.89' LT	800.56
G	155+67.77	20.11' LT	801.07
H	155+67.44	21.65' LT	801.06
I	155+67.49	28.43' LT	801.09
J	155+67.54	35.23' LT	800.62
K	155+67.93	45.22' LT	800.47
L	155+57.80	45.57' LT	800.54
M	155+57.56	37.58' LT	800.66
N	155+57.54	35.33' LT	800.69
O	155+57.51	28.53' LT	801.02
P	155+57.43	19.89' LT	800.97
Q	155+57.65	18.32' LT	800.98
R	155+49.92	37.81' LT	800.73
S	155+50.14	45.80' LT	800.61
T	155+42.44	46.03' LT	800.69
U	155+42.22	38.03' LT	800.81
V	155+34.52	38.25' LT	800.88
W	155+34.73	46.25' LT	800.76
X	155+27.03	46.46' LT	800.83
Y	155+26.83	38.46' LT	800.95
Z	155+67.51	5.77' LT	801.32
AA	155+67.35	3.03' RT	801.27
AB	155+57.35	4.16' LT	801.25
AC	155+57.20	3.00' RT	801.21
AD	155+81.45	43.42' RT	(801.51)
AE	155+81.82	48.71' RT	(801.48)
AF	155+66.59	49.10' RT	801.49
AG	155+66.46	43.99' RT	801.50
AH	155+66.61	35.19' RT	801.31
AI	155+66.77	26.39' RT	801.12
AJ	155+66.89	19.17' RT	800.97
AK	155+67.08	17.60' RT	800.98
AL	155+56.90	17.00' RT	800.93
AM	155+56.90	18.58' RT	800.92
AN	155+56.76	26.22' RT	801.09
AO	155+56.60	35.02' RT	801.28
AP	155+56.43	44.37' RT	801.49
AQ	155+56.56	49.37' RT	801.50
AR	155+40.93	49.69' RT	(801.54)
AS	155+40.86	44.84' RT	(801.52)



MODEL: ADA-11 [Sheet]
FILE NAME: c:\bns\civil\tech-pw\patro.kravets\0140567\3983 ADA Curb Ramps.dgn

USER NAME = pk	DESIGNED - AMP	REVISED -
	DRAWN - AMP	REVISED -
	CHECKED - PK	REVISED -
	DATE - 12/12/2025	REVISED -
PLOT DATE = 12/15/2025		


STATE OF ILLINOIS
DEPARTMENT OF TRANSPORTATION

BRAINTREE DRIVE
ADA GRADING PLAN

SCALE: 1" = 5' SHEET 11 OF 17 SHEETS STA. TO STA.

MUN RTE.	SECTION	COUNTY	TOTAL SHEETS	SHEET NO.
4029	23-00146-00-PV	COOK	315	142
CONTRACT NO. 61M26				
ILLINOIS FED. AID PROJECT				

MODEL: ADA-12 (Sheet)
FILE NAME: c:\bns\citytech-pw\patro.kravets\01405673993 ADA Curb Ramps.dgn

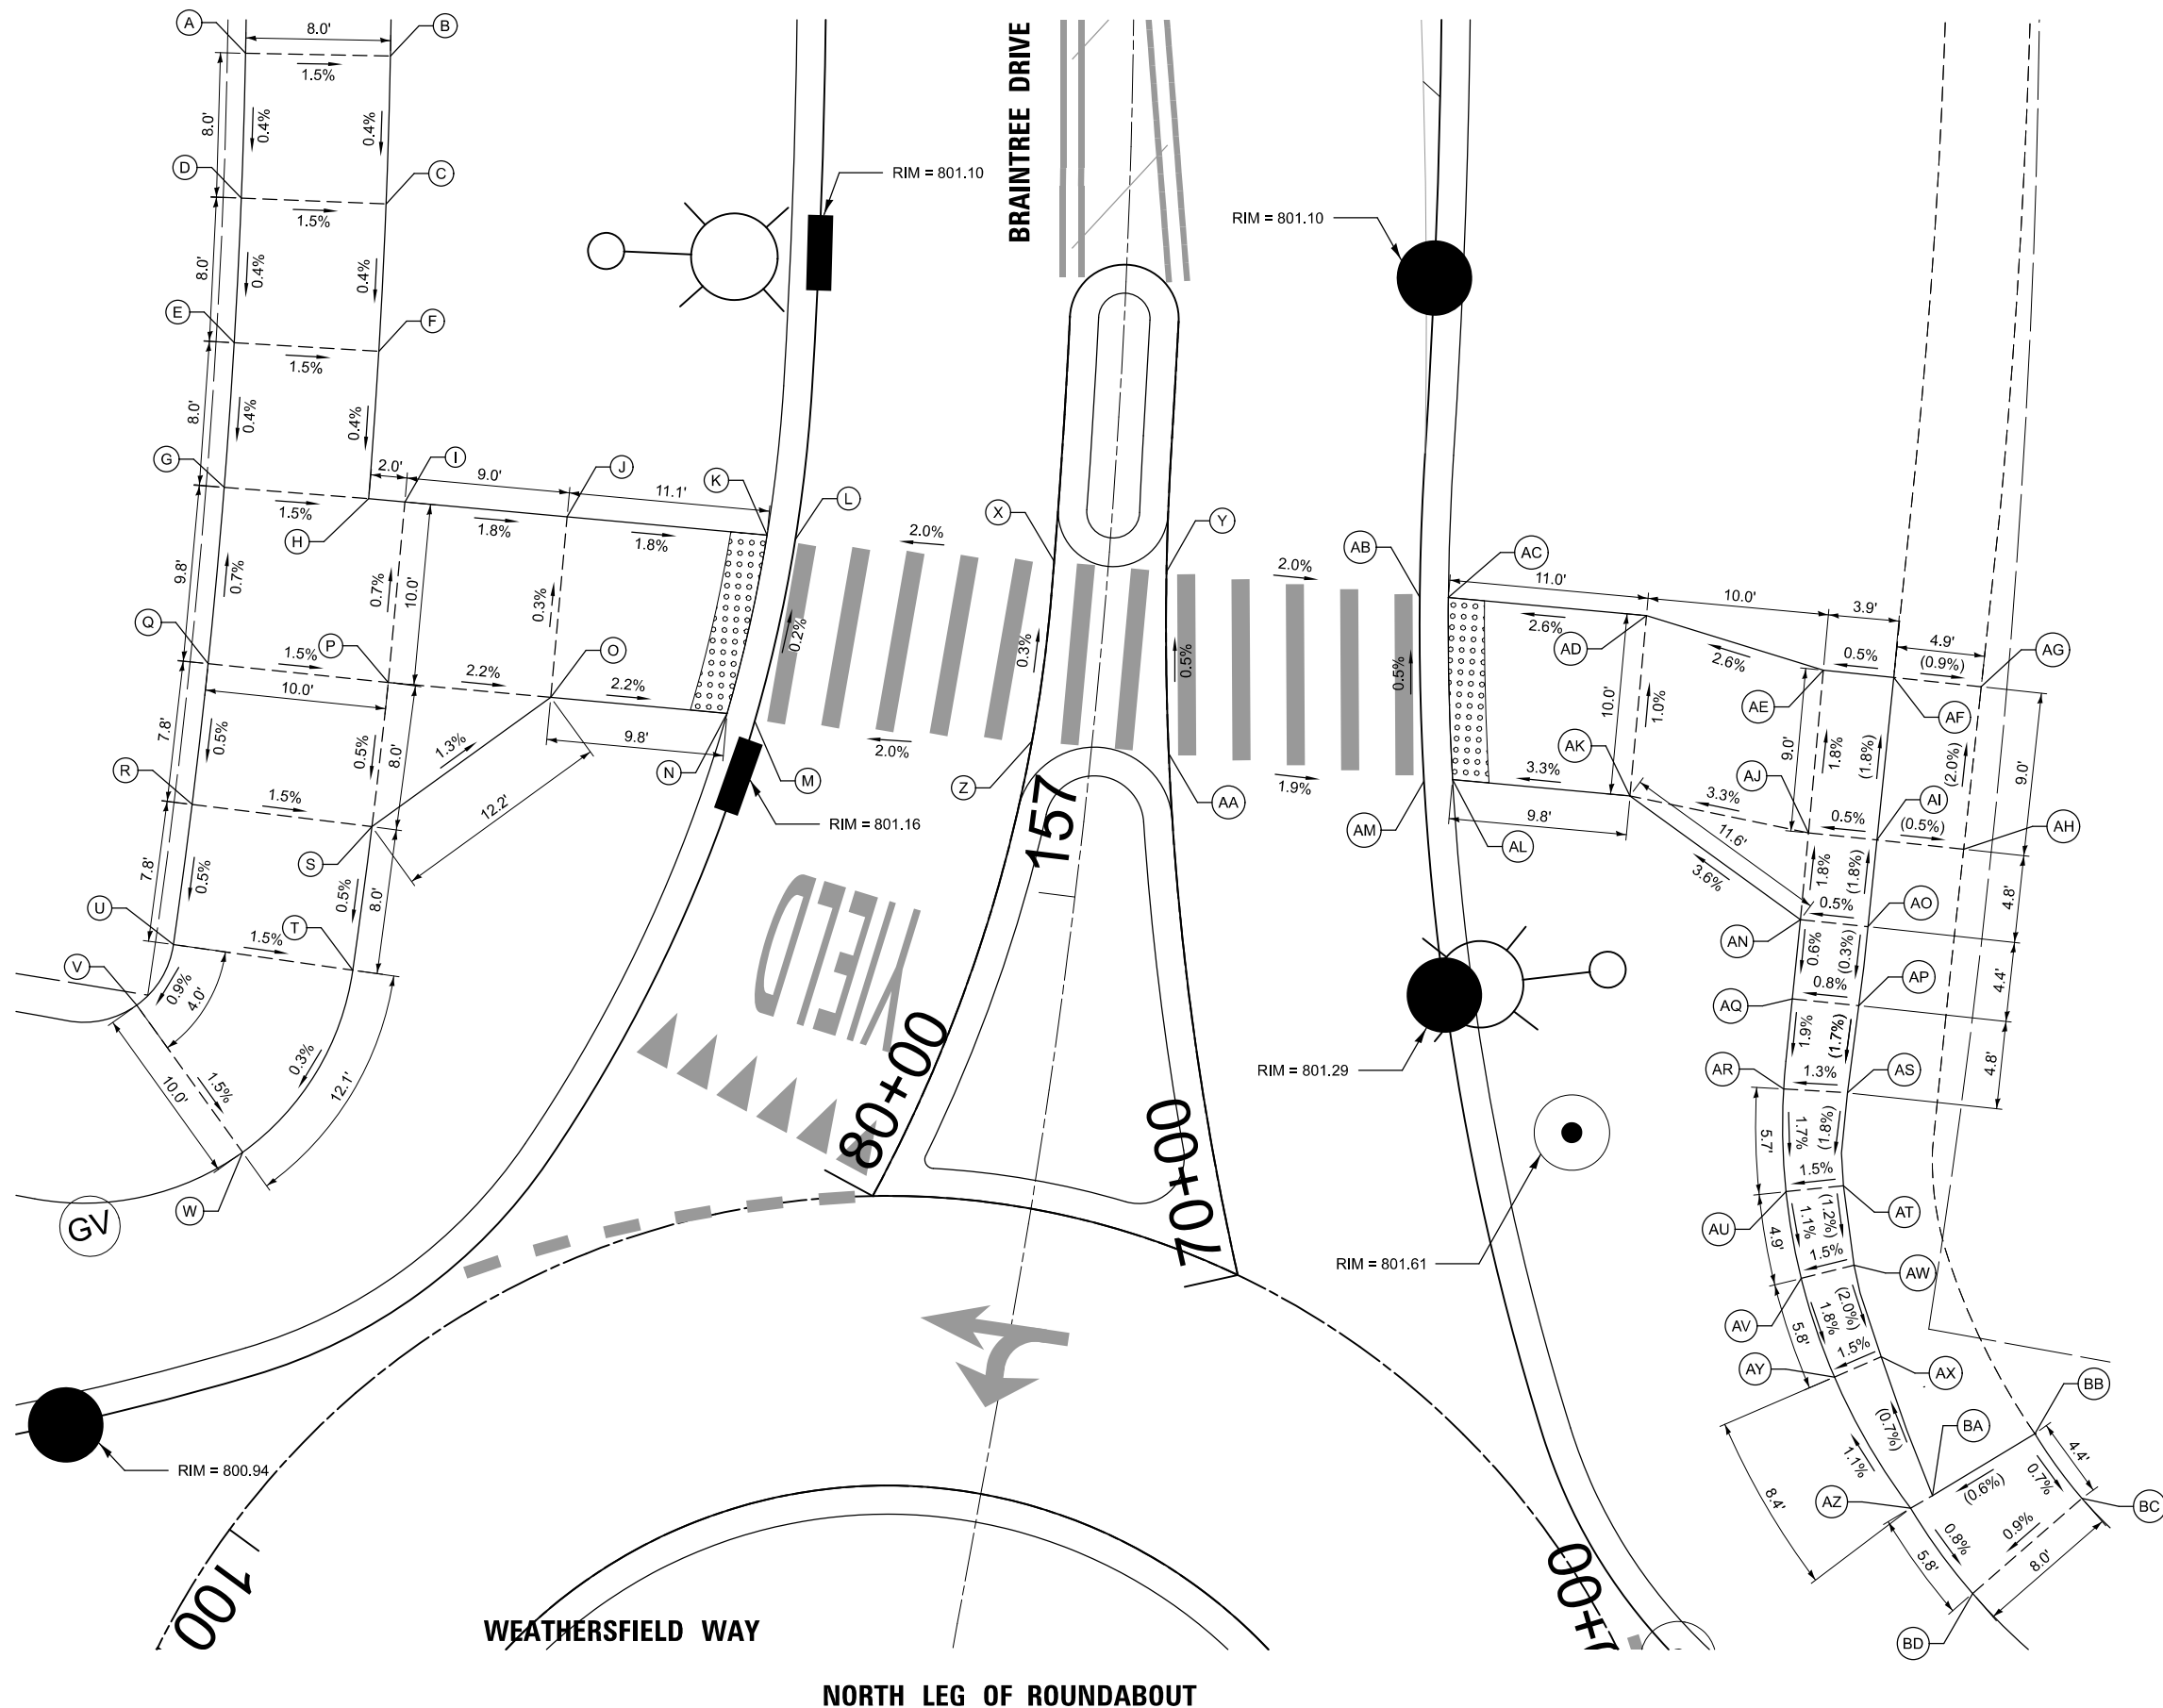

POINT	STATION	OFFSET	ELEVATION
A	157+45.78	49.00' LT	801.74
B	157+45.78	41.00' LT	801.62
C	157+36.81	41.00' LT	801.58
D	157+36.81	49.00' LT	801.70
E	157+27.83	49.00' LT	801.67
F	157+27.83	41.00' LT	801.55
G	157+18.85	49.00' LT	801.64
H	157+18.85	41.00' LT	801.52
I	157+18.82	39.00' LT	801.49
J	157+18.71	30.00' LT	801.33
K	157+18.57	18.91' LT	801.12
L	157+18.44	17.34' LT	801.13
M	157+07.82	18.66' LT	801.15
N	157+08.12	20.21' LT	801.14
O	157+07.99	30.00' LT	801.36
P	157+07.88	39.00' LT	801.56
Q	157+07.88	49.00' LT	801.71
R	156+99.09	49.00' LT	801.67
S	156+99.09	39.00' LT	801.52
T	156+90.34	39.00' LT	801.47
U	156+90.34	49.00' LT	801.62
V	156+86.28	50.52' LT	801.59
W	156+78.37	43.46' LT	801.44
X	157+18.38	3.00' LT	801.42
Y	157+18.31	3.23' RT	801.45
Z	157+08.31	3.31' LT	801.45
AA	157+08.40	4.27' RT	801.49
AB	157+18.04	17.28' RT	801.17
AC	157+18.15	18.85' RT	801.16
AD	157+18.04	29.84' RT	801.45
AE	157+16.00	39.82' RT	801.72
AF	157+15.94	43.73' RT	(801.74)
AG	157+15.84	48.58' RT	(801.70)
AH	157+07.70	48.47' RT	(801.87)
AI	157+07.72	43.65' RT	(801.90)
AJ	157+07.71	39.85' RT	801.88
AK	157+08.66	29.84' RT	801.55
AL	157+08.56	20.00' RT	801.22
AM	157+08.32	18.44' RT	801.23
AN	157+03.29	39.94' RT	801.97
AO	157+03.33	43.68' RT	(801.99)
AP	156+99.32	43.69' RT	(801.97)
AQ	156+99.25	40.00' RT	801.94
AR	156+94.66	40.16' RT	801.85
AS	156+94.90	43.67' RT	(801.89)
AT	156+90.24	44.16' RT	(801.80)
AU	156+89.53	41.07' RT	801.75
AV	156+85.31	42.61' RT	801.70
AW	156+86.36	45.38' RT	(801.74)
AX	156+82.04	47.64' RT	(801.64)
AY	156+80.67	45.28' RT	801.60
AZ	156+74.86	50.66' RT	801.69
BA	156+75.67	51.73' RT	(801.70)
BB	156+79.53	56.72' RT	(801.74)
BC	156+76.80	59.87' RT	801.71
BD	156+70.97	54.86' RT	801.64



USER NAME = pk	DESIGNED - AMP	REVISED -
	DRAWN - AMP	REVISED -
	CHECKED - PK	REVISED -
PLOT DATE = 12/15/2025	DATE - 12/12/2025	REVISED -

STATE OF ILLINOIS
DEPARTMENT OF TRANSPORTATION

BRAINTREE DRIVE
ADA GRADING PLAN


SCALE: 1" = 5' SHEET 12 OF 17 SHEETS STA. TO STA.

MUN RTE.	SECTION	COUNTY	TOTAL SHEETS	SHEET NO.
4029	23-00146-00-PV	COOK	315	143
CONTRACT NO. 61M26				
ILLINOIS FED. AID PROJECT				



POINT	STATION	OFFSET	ELEVATION
A	400+95.06	19.06' LT	801.97
B	401+01.98	19.03' LT	801.94
C	401+01.99	20.61' LT	801.93
D	400+95.07	20.64' LT	801.96
E	401+06.88	32.74' LT	802.36
F	401+10.32	29.23' LT	802.26
G	401+18.51	37.92' LT	802.59
H	401+15.07	41.40' LT	802.67
I	401+16.52	42.96' LT	802.73
J	401+13.74	44.10' LT	802.74
K	401+08.73	44.10' LT	(802.70)
L	401+08.72	48.96' LT	(802.86)
M	401+13.74	48.97' LT	802.84
N	401+21.35	48.99' LT	802.83
O	401+21.35	40.99' LT	802.71
P	401+28.93	40.97' LT	802.73
Q	401+28.96	48.97' LT	802.82
R	401+36.56	48.93' LT	802.82
S	401+36.51	40.93' LT	802.71
T	401+44.09	40.86' LT	802.69
U	401+44.17	48.86' LT	802.81
V	401+50.16	48.78' LT	(802.75)
W	401+51.78	48.76' LT	(802.74)
X	401+51.70	40.76' LT	802.62
Y	401+59.37	40.71' LT	802.54
Z	401+59.39	48.71' LT	(802.66)
AA	401+67.00	48.72' LT	(802.59)
AB	401+67.46	48.72' LT	(802.59)
AC	401+67.04	40.72' LT	802.47
AD	401+74.68	40.80' LT	802.40
AE	401+74.61	48.80' LT	802.52
AF	401+82.22	48.87' LT	802.42
AG	401+82.27	40.87' LT	802.30

LEGEND
 TACTILE DIRECTIONAL INDICATOR

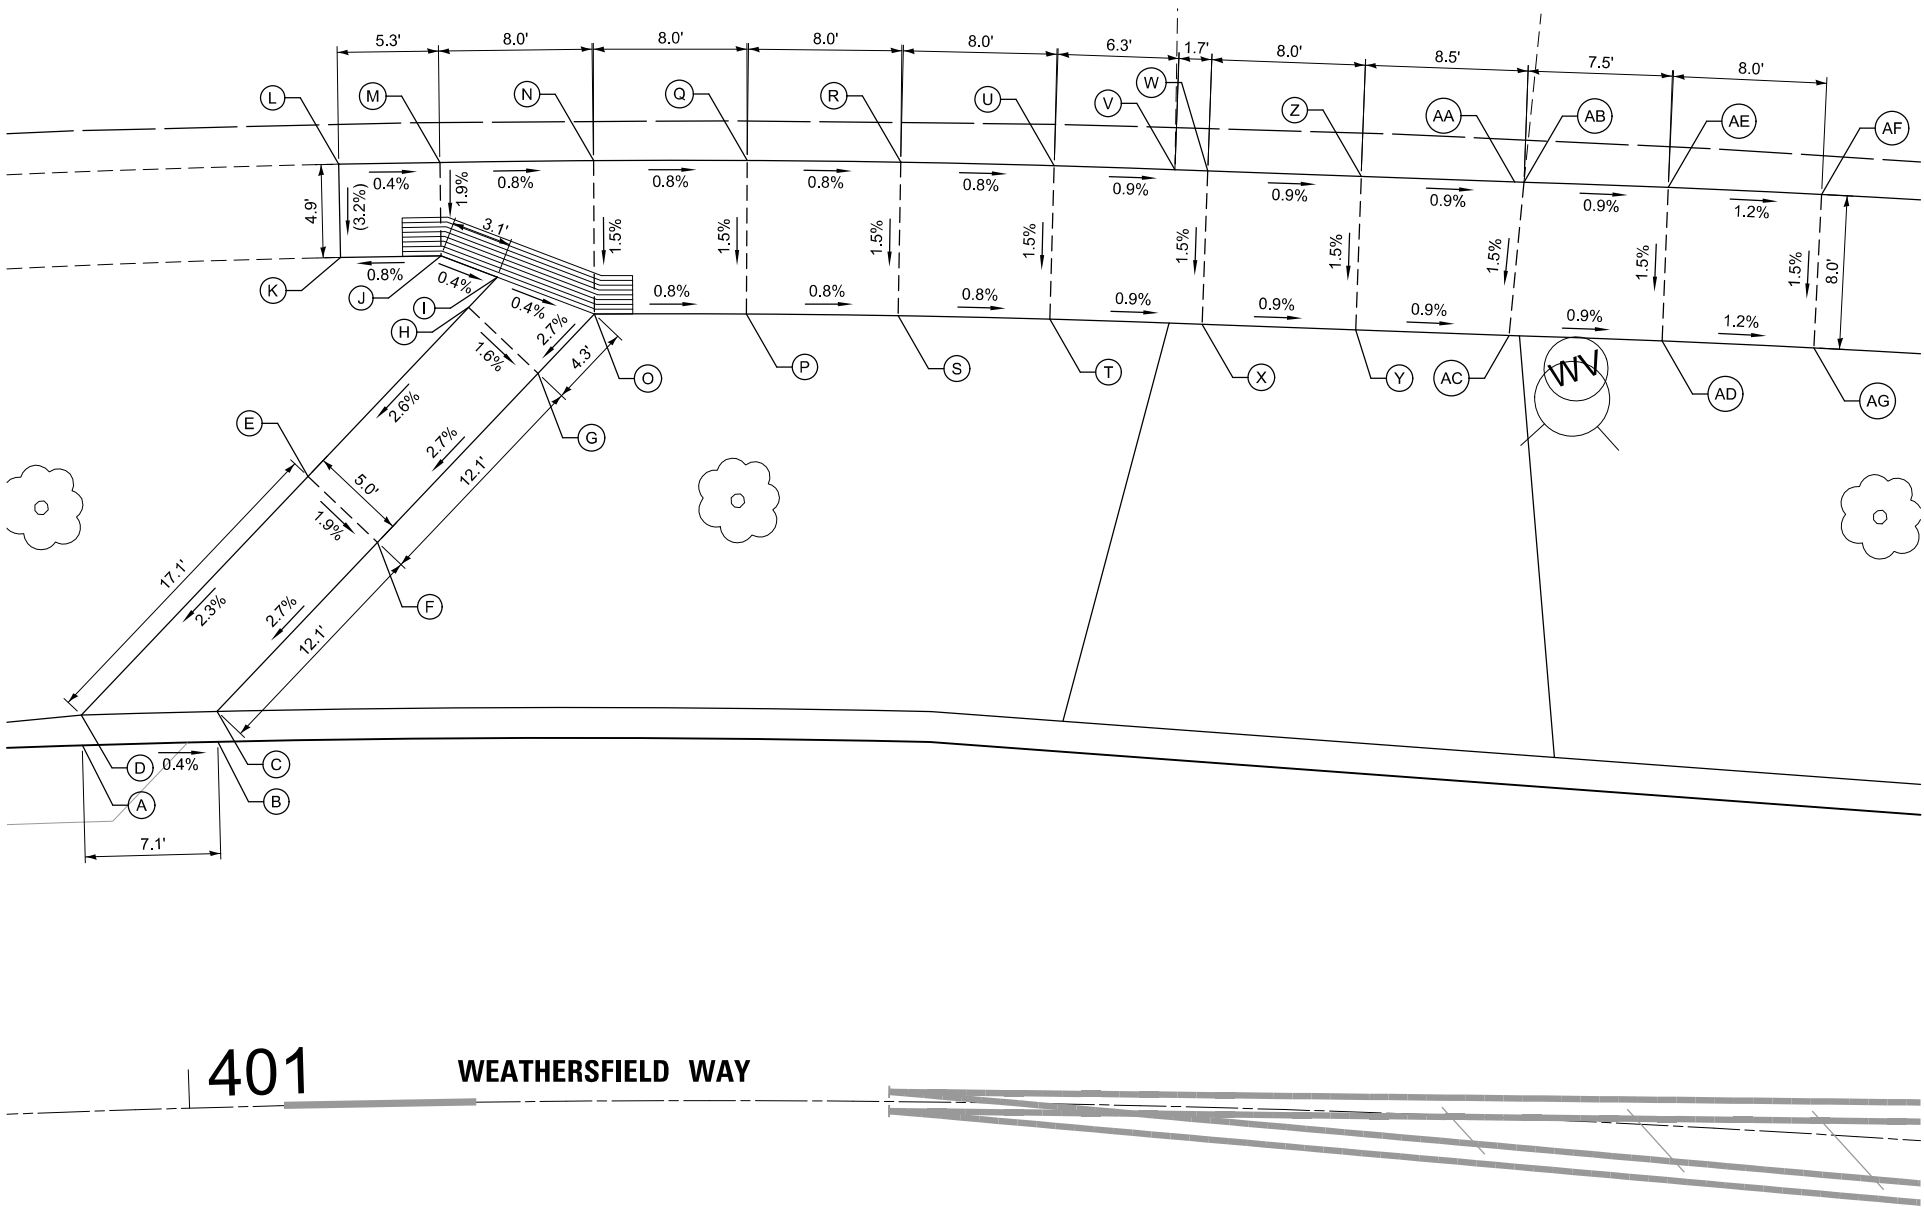

STATE OF ILLINOIS
DEPARTMENT OF TRANSPORTATION


BRAINTREE DRIVE
ADA GRADING PLAN

MUN. RTE.	SECTION	COUNTY	TOTAL SHEETS	SHEET NO.
4029	23-00146-00-PV	COOK	315	144
CONTRACT NO. 61M26				
ILLINOIS FED. AID PROJECT				

USER NAME = pk	DESIGNED - AMP	REVISED -
	DRAWN - AMP	REVISED -
	CHECKED - PK	REVISED -
PLOT DATE = 12/15/2025	DATE - 12/12/2025	REVISED -

SCALE: 1" = 5' SHEET 13 OF 17 SHEETS STA. TO STA.

MODEL: ADA-13 (Sheet)
FILE NAME: c:\bns\sch\ilch-pw\patro.kravets\014056713983 ADA Curb Ramps.dgn

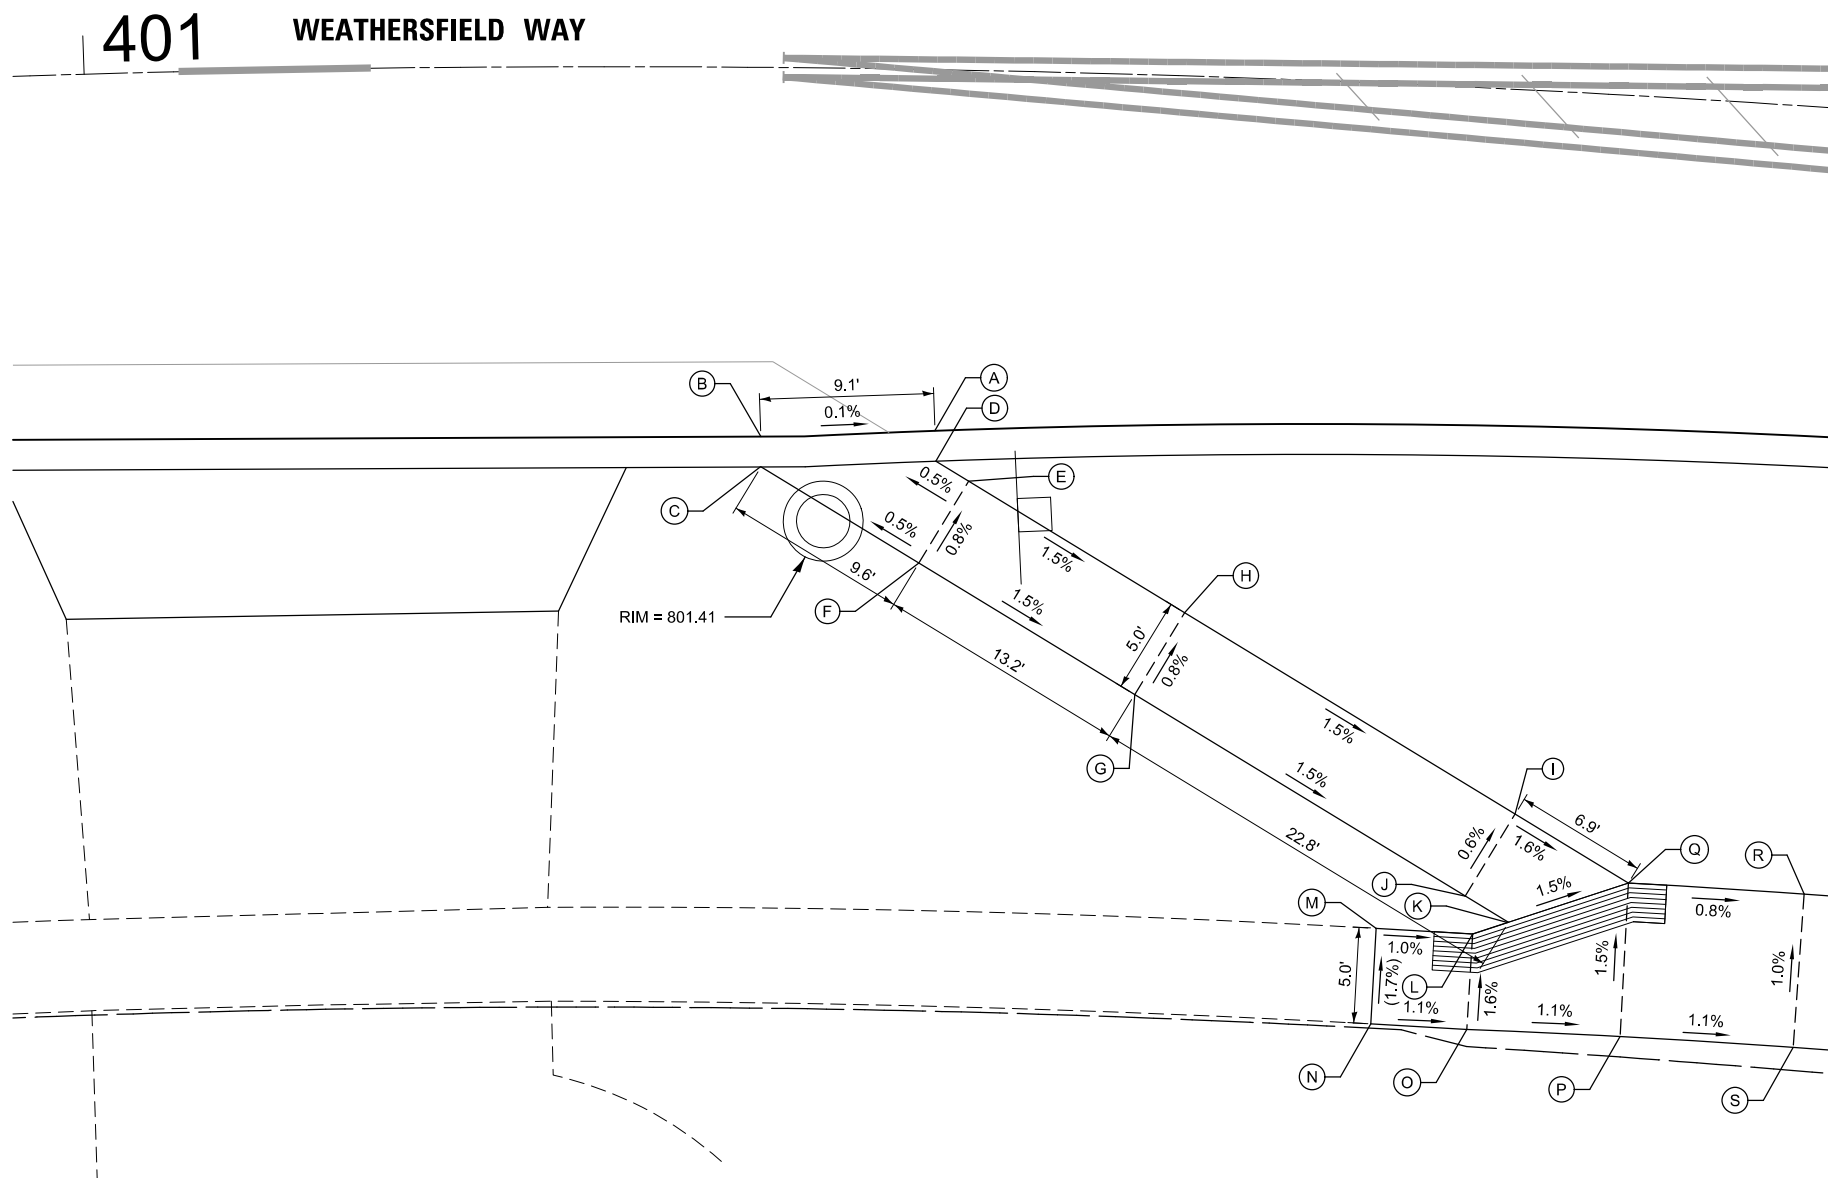


POINT	STATION	OFFSET	ELEVATION
A	401+44.67	18.81' RT	801.40
B	401+35.42	19.23' RT	801.40
C	401+35.45	20.81' RT	801.39
D	401+44.75	20.39' RT	801.39
E	401+46.52	21.39' RT	801.40
F	401+43.94	25.71' RT	801.44
G	401+55.70	32.29' RT	801.24
H	401+58.25	27.94' RT	801.20
I	401+76.52	37.70' RT	800.90
J	401+74.03	42.09' RT	800.93
K	401+76.46	43.35' RT	800.89
L	401+74.54	44.05' RT	800.92
M	401+69.27	43.99' RT	(800.97)
N	401+69.21	48.98' RT	(801.05)
O	401+74.48	49.03' RT	801.00
P	401+82.91	48.96' RT	800.91
Q	401+82.87	40.96' RT	800.79
R	401+92.46	40.95' RT	800.72
S	401+92.44	48.95' RT	800.81

 TACTILE DIRECTIONAL INDICATOR

	USER NAME = pk	DESIGNED - AMP	REVISED -	STATE OF ILLINOIS DEPARTMENT OF TRANSPORTATION	BRAINTREE DRIVE ADA GRADING PLAN			MUN RTE.	SECTION	COUNTY	TOTAL SHEETS	SHEET NO.
		DRAWN - AMP	REVISED -					4029	23-00146-00-PV	COOK	315	145
		CHECKED - PK	REVISED -					CONTRACT NO. 61M26				
	PLOT DATE = 12/15/2025	DATE - 12/12/2025	REVISED -		SCALE: 1" = 5'	SHEET 14 OF 17 SHEETS	STA. TO STA.	ILLINOIS FED. AID PROJECT				

MODEL: ADA-16 (Sheet)
FILE NAME: c:\bns\st\illic\ch-pw\patro.kravets\dd14056713993 ADA Curb Ramps.dgn

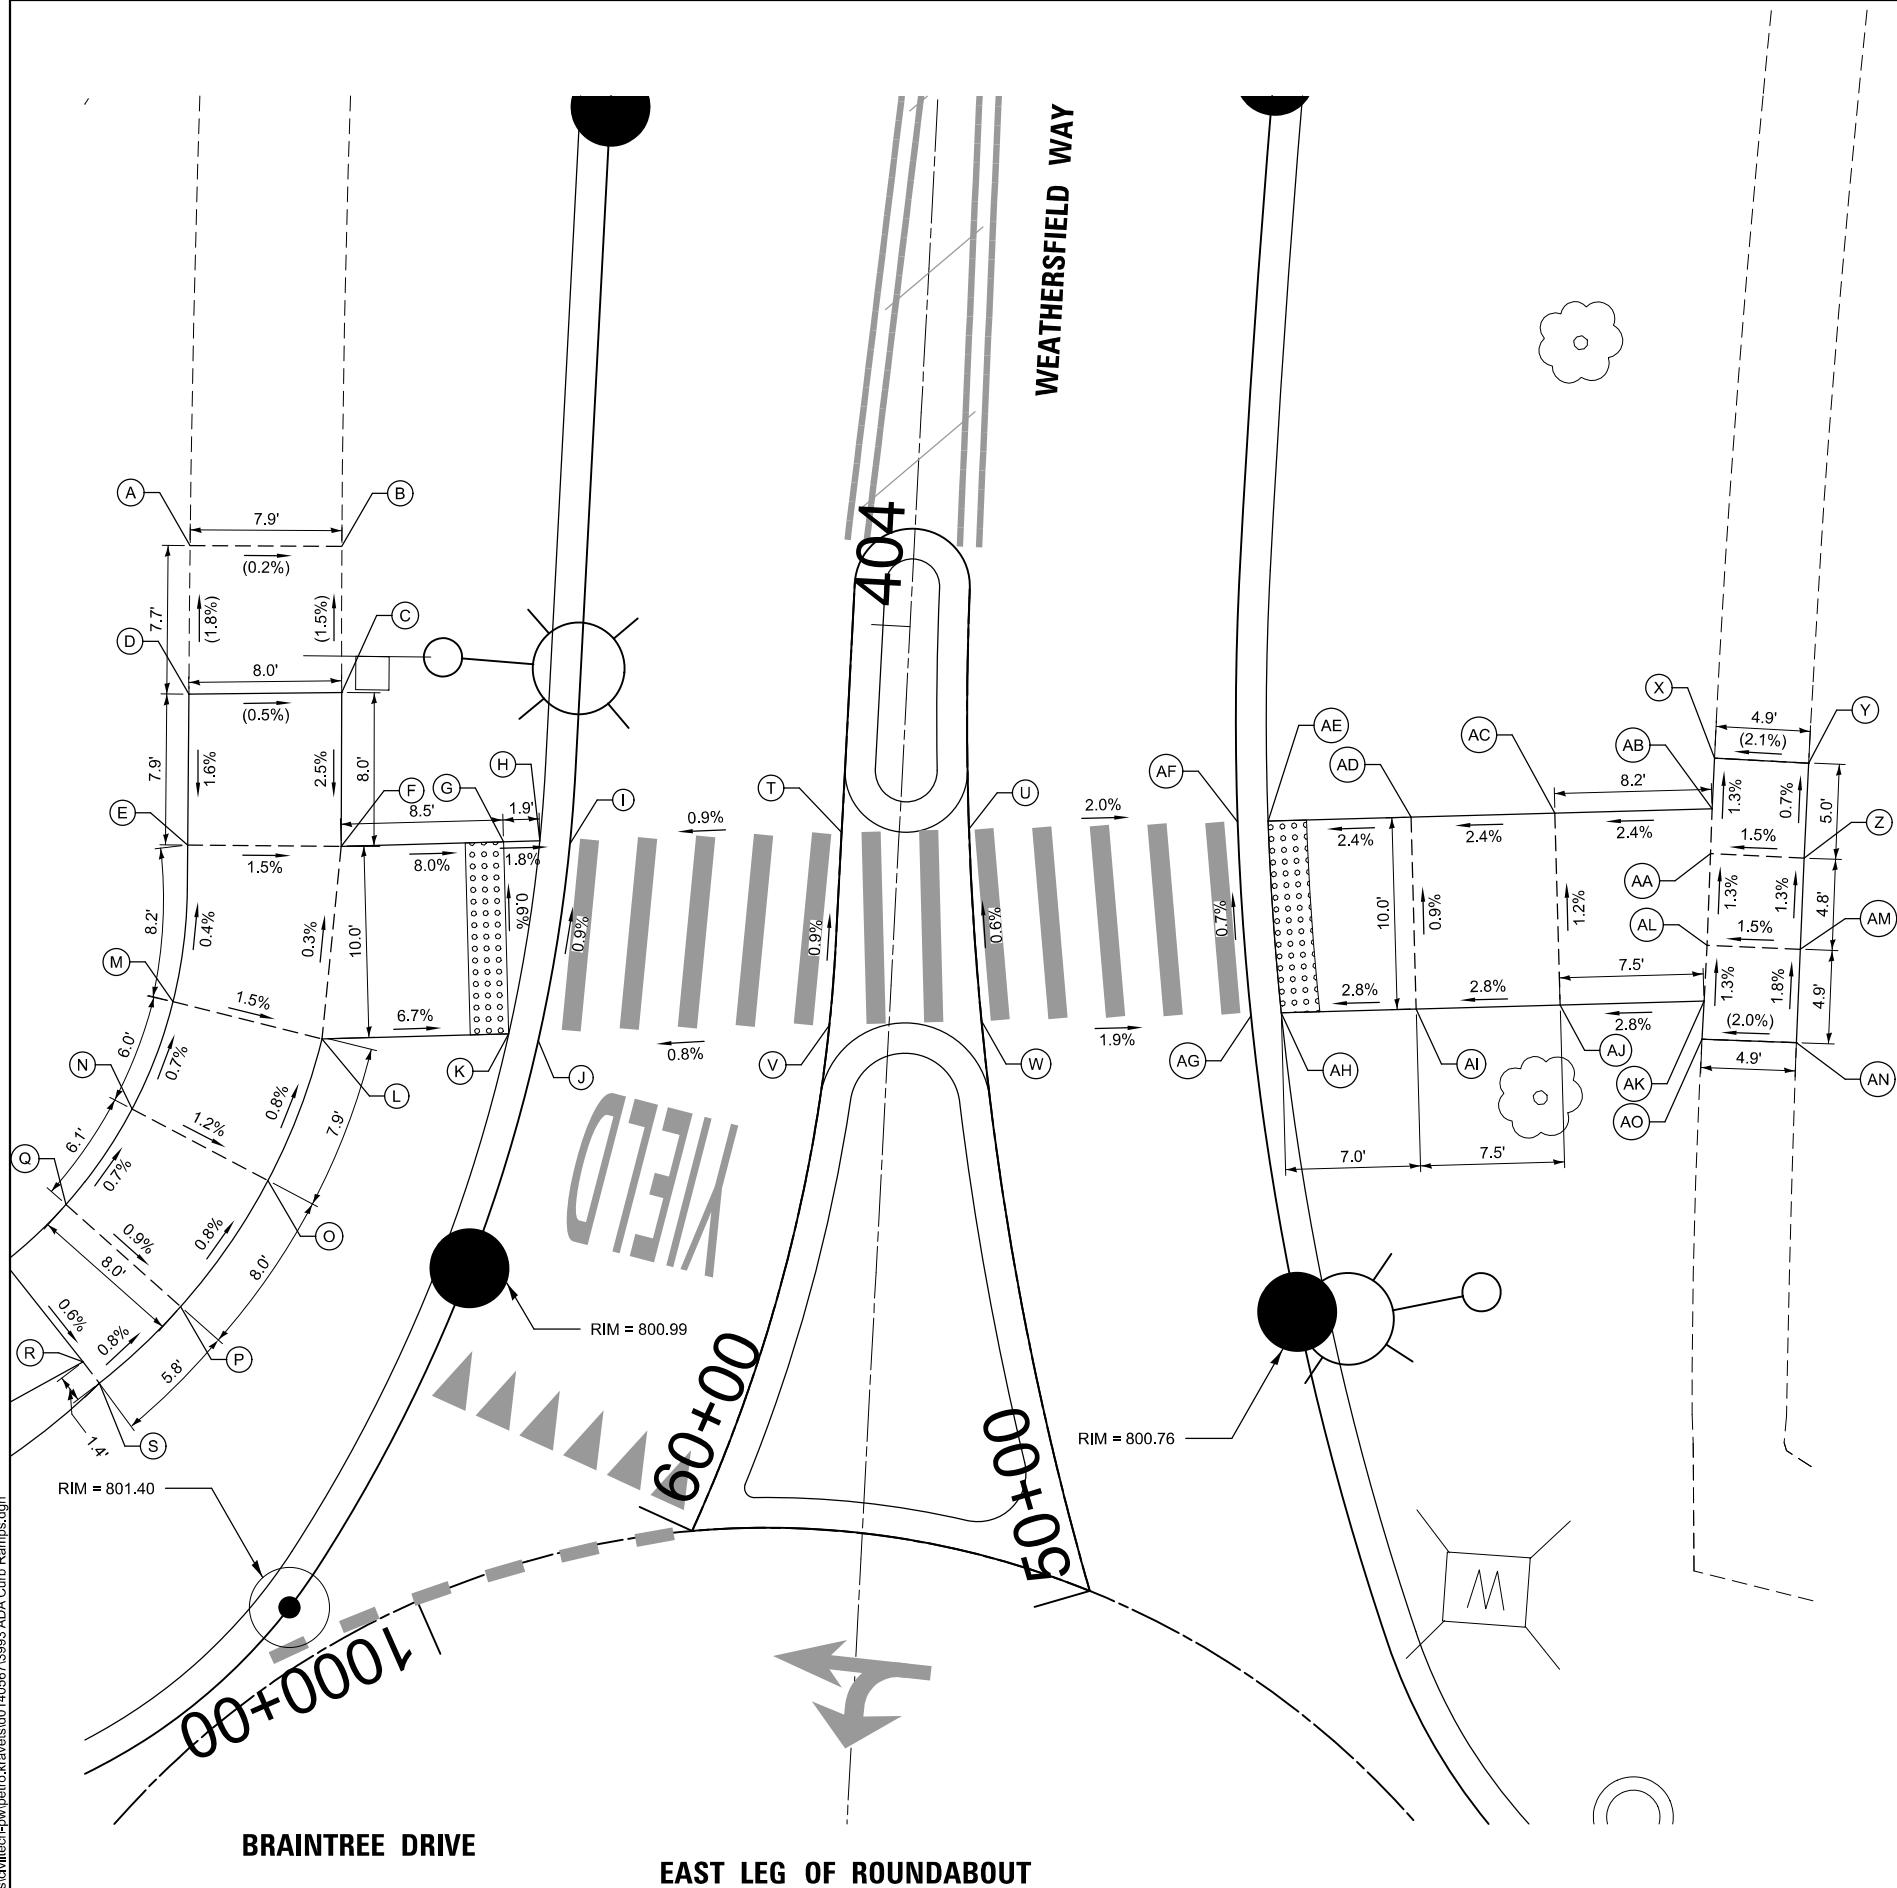

POINT	STATION	OFFSET	ELEVATION
A	404+02.25	37.67' LT	(801.58)
B	404+02.62	29.77' LT	(801.57)
C	403+95.01	29.38' LT	(801.68)
D	403+94.51	37.32' LT	(801.72)
E	403+86.66	36.97' LT	801.60
F	403+87.02	28.98' LT	801.48
G	403+87.69	20.55' LT	800.80
H	403+87.84	18.67' LT	800.77
I	403+87.77	17.09' LT	800.78
J	403+77.46	18.20' LT	800.87
K	403+77.72	19.75' LT	800.86
L	403+76.95	29.45' LT	801.51
M	403+78.47	37.30' LT	801.63
N	403+72.78	39.14' LT	801.67
O	403+69.43	31.88' LT	801.58
P	403+62.64	36.07' LT	801.64
Q	403+67.64	42.32' LT	801.71
R	403+59.50	41.00' LT	801.70
S	403+58.43	40.09' LT	801.69
T	403+89.10	2.99' LT	800.91
U	403+89.63	3.62' RT	800.87
V	403+79.06	3.10' LT	801.00
W	403+79.69	4.80' RT	800.93
X	403+95.36	42.20' RT	(801.10)
Y	403+95.36	47.11' RT	(801.20)
Z	403+90.41	47.13' RT	801.24
AA	403+90.38	42.25' RT	801.16
AB	403+92.72	42.22' RT	801.13
AC	403+92.07	34.05' RT	800.94
AD	403+91.47	26.57' RT	800.76
AE	403+90.87	19.15' RT	800.58
AF	403+90.73	17.58' RT	800.59
AG	403+80.69	18.80' RT	800.66
AH	403+80.94	20.37' RT	800.65
AI	403+81.50	27.37' RT	800.85
AJ	403+82.10	34.85' RT	801.05
AK	403+82.70	42.33' RT	801.26
AL	403+85.61	42.33' RT	801.22
AM	403+85.66	47.17' RT	801.30
AN	403+80.79	47.24' RT	(801.39)
AO	403+80.71	42.32' RT	(801.29)



PLOT DATE = 12/15/2025	USER NAME = pk	DESIGNED - AMP	REVISED -
		DRAWN - AMP	REVISED -
		CHECKED - PK	REVISED -
	DATE - 12/12/2025		REVISED -


STATE OF ILLINOIS
DEPARTMENT OF TRANSPORTATION

BRAINTREE DRIVE
ADA GRADING PLAN

SCALE: 1" = 5' SHEET 16 OF 17 SHEETS STA. TO STA.

MUN RTE.	SECTION	COUNTY	TOTAL SHEETS	SHEET NO.
4029	23-00146-00-PV	COOK	315	147
CONTRACT NO. 61M26				
ILLINOIS FED. AID PROJECT				

MODEL: ADA-17 (Sheet)
FILE NAME: c:\bns\sl\ilich-pw\patro.kravets\0140567\3993 ADA Curb Ramps.dgn

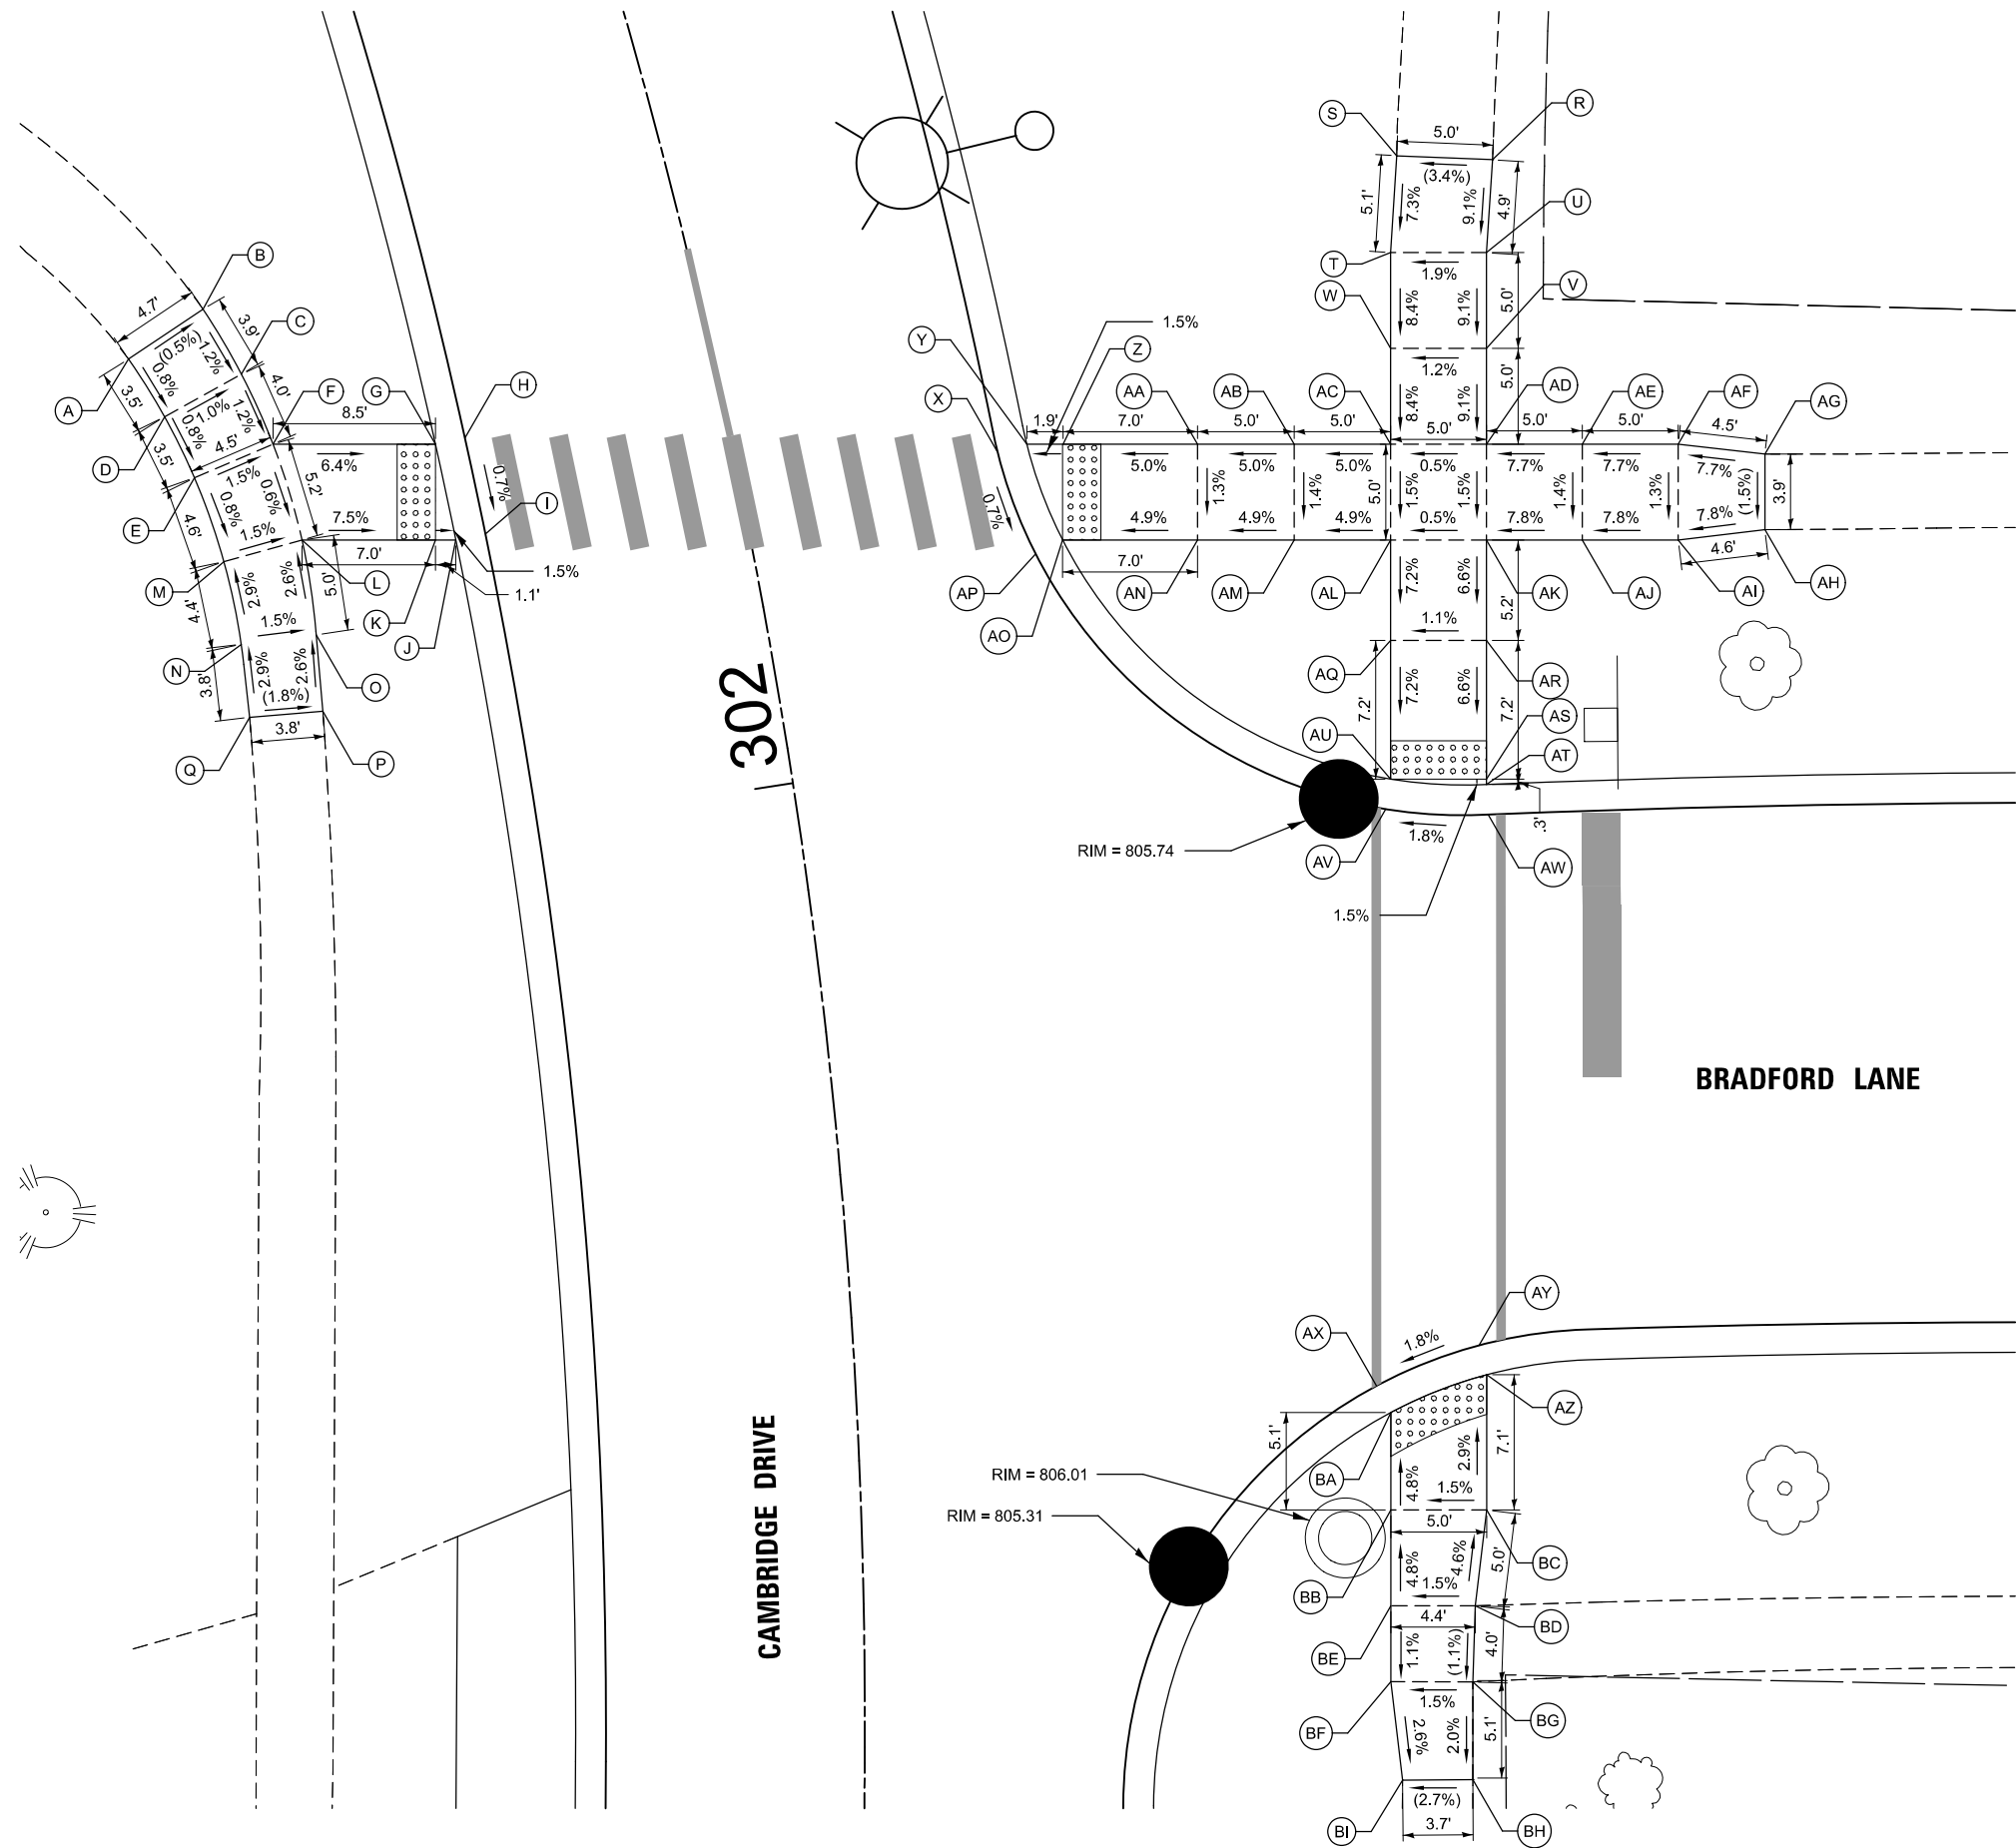

POINT	STATION	OFFSET	ELEVATION
A	302+29.90	29.64' LT	(806.38)
B	302+31.62	25.24' LT	(806.35)
C	302+27.54	24.11' LT	806.30
D	302+26.20	28.53' LT	806.35
E	302+22.42	27.72' LT	806.32
F	302+23.29	23.35' LT	806.25
G	302+21.32	15.08' LT	805.71
H	302+21.32	13.50' LT	805.72
I	302+15.95	13.50' LT	805.69
J	302+15.95	15.08' LT	805.68
K	302+16.18	16.12' LT	805.70
L	302+17.68	22.94' LT	806.22
M	302+17.39	27.15' LT	806.28
N	302+12.58	27.12' LT	806.41
O	302+12.31	23.18' LT	806.35
P	302+08.02	23.58' LT	(806.45)
Q	302+08.41	27.38' LT	(806.52)
R	302+23.78	41.71' RT	(808.12)
S	302+24.78	36.84' RT	(807.95)
T	302+20.40	35.73' RT	807.59
U	302+19.45	40.62' RT	807.68
V	302+15.09	39.60' RT	807.23
W	302+15.99	34.70' RT	807.17
X	302+14.87	13.52' RT	805.87
Y	302+14.94	15.10' RT	805.86
Z	302+14.59	16.94' RT	805.89
AA	302+13.30	23.84' RT	806.24
AB	302+12.41	28.78' RT	806.49
AC	302+11.55	33.73' RT	806.74
AD	302+10.71	38.64' RT	806.77
AE	302+09.90	43.56' RT	807.15
AF	302+09.11	48.48' RT	807.54
AG	302+08.34	53.40' RT	(807.88)
AH	302+04.11	52.54' RT	(807.83)
AI	302+04.82	47.61' RT	807.47
AJ	302+05.56	42.68' RT	807.08
AK	302+06.31	37.76' RT	806.69
AL	302+07.09	32.83' RT	806.67
AM	302+07.89	27.87' RT	806.42
AN	302+08.72	22.91' RT	806.18
AO	302+09.91	16.00' RT	805.84
AP	302+09.48	14.48' RT	805.84
AQ	302+02.39	31.96' RT	806.29
AR	302+01.68	36.90' RT	806.35
AS	301+95.25	35.83' RT	805.87
AT	301+95.00	35.80' RT	805.86
AU	301+95.87	30.88' RT	805.77
AV	301+94.49	30.42' RT	805.77
AW	301+93.58	35.67' RT	805.87
AX	301+67.01	27.15' RT	805.66
AY	301+68.68	32.59' RT	805.77
AZ	301+67.28	32.92' RT	805.77
BA	301+65.70	27.82' RT	805.66
BB	301+61.01	27.63' RT	805.90
BC	301+60.87	32.62' RT	805.97
BD	301+56.33	31.90' RT	(806.20)
BE	301+56.41	27.50' RT	806.14
BF	301+52.76	27.45' RT	806.10
BG	301+52.72	31.72' RT	(806.16)
BH	301+48.02	31.73' RT	(806.06)
BI	301+47.97	28.06' RT	(805.96)




USER NAME = pk	DESIGNED - AMP	REVISED -
	DRAWN - AMP	REVISED -
	CHECKED - PK	REVISED -
	DATE - 12/12/2025	REVISED -

STATE OF ILLINOIS
DEPARTMENT OF TRANSPORTATION


BRAINTREE DRIVE
ADA GRADING PLAN

SCALE: 1" = 5' SHEET 17 OF 17 SHEETS STA. TO STA.

MUN RTE.	SECTION	COUNTY	TOTAL SHEETS	SHEET NO.
4029	23-00146-00-PV	COOK	315	148
CONTRACT NO. 61M26				
ILLINOIS FED. AID PROJECT				

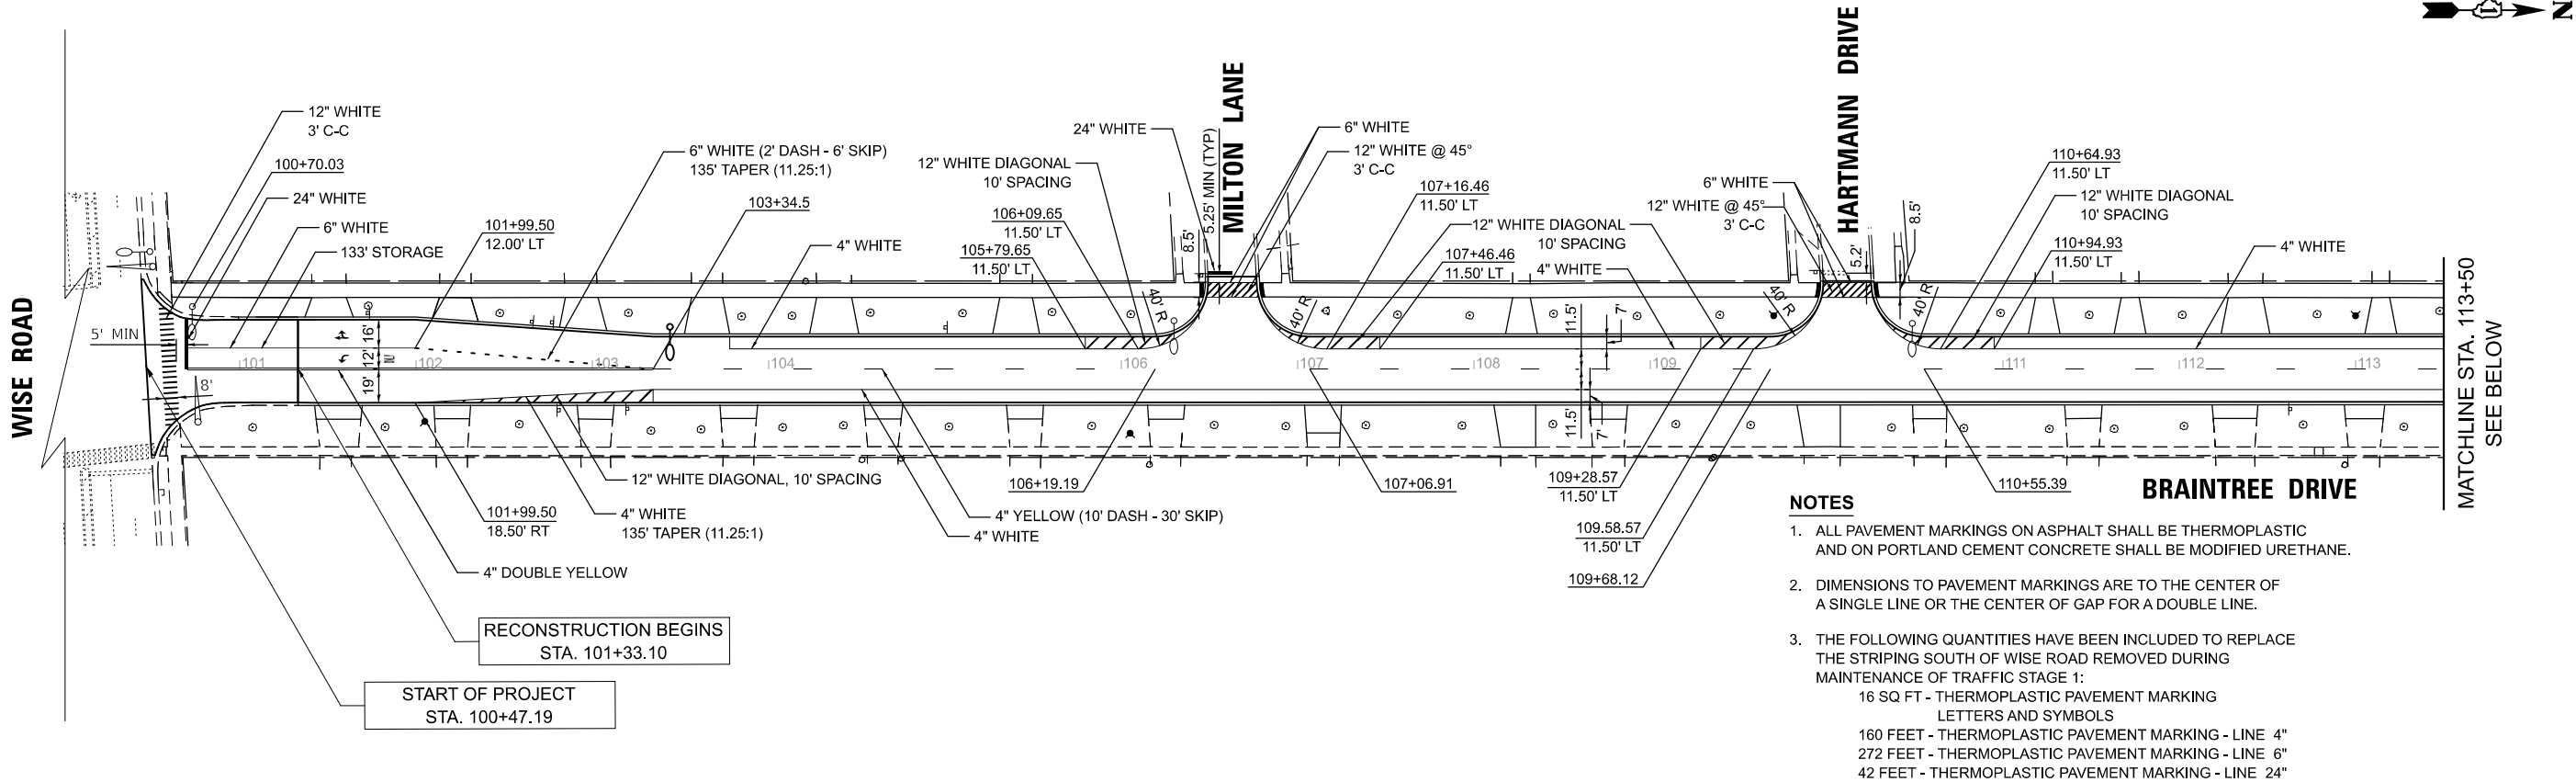

- NOTES**
- ALL PAVEMENT MARKINGS ON ASPHALT SHALL BE THERMOPLASTIC AND ON PORTLAND CEMENT CONCRETE SHALL BE MODIFIED URETHANE.
 - DIMENSIONS TO PAVEMENT MARKINGS ARE TO THE CENTER OF A SINGLE LINE OR THE CENTER OF GAP FOR A DOUBLE LINE.
 - THE FOLLOWING QUANTITIES HAVE BEEN INCLUDED TO REPLACE THE STRIPING SOUTH OF WISE ROAD REMOVED DURING MAINTENANCE OF TRAFFIC STAGE 1:
16 SQ FT - THERMOPLASTIC PAVEMENT MARKING LETTERS AND SYMBOLS
160 FEET - THERMOPLASTIC PAVEMENT MARKING - LINE 4"
272 FEET - THERMOPLASTIC PAVEMENT MARKING - LINE 6"
42 FEET - THERMOPLASTIC PAVEMENT MARKING - LINE 24"

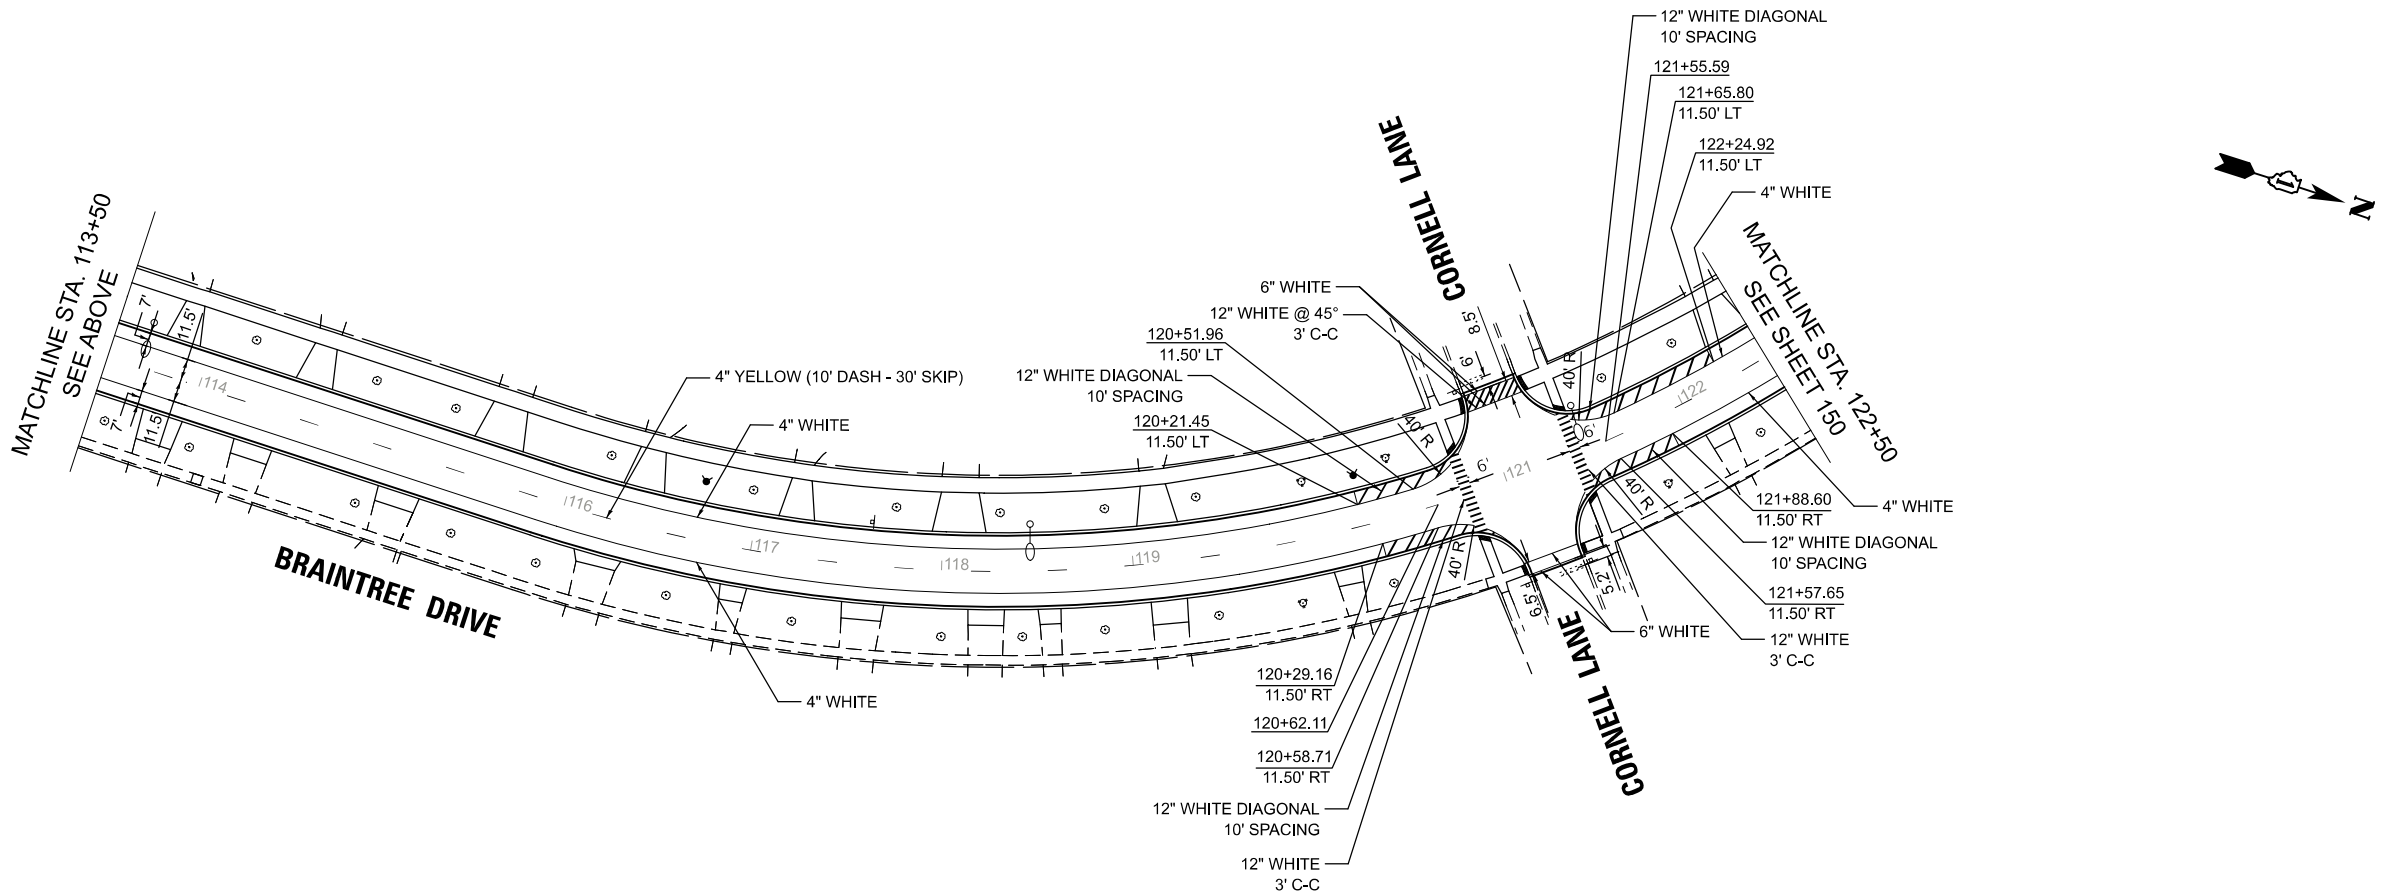

MODEL: Braintree - Plan 1 [Sheet]
FILE NAME: c:\bms\stl\tech-pw\patro.kravets\dd140568\3983 PMK Sheets.dgn

USER NAME	= pk	DESIGNED -	AMP	REVISED -	
		DRAWN -	AMP	REVISED -	
		CHECKED -	PK	REVISED -	
PLOT DATE	= 12/15/2025	DATE	= 12/12/2025	REVISED -	



STATE OF ILLINOIS
DEPARTMENT OF TRANSPORTATION

BRAINTREE DRIVE
PAVEMENT MARKING PLAN

SCALE: 1"=50' SHEET 1 OF 4 SHEETS STA. 100+00.00 TO STA. 122+50.00

MUN RTE.	SECTION	COUNTY	TOTAL SHEETS	SHEET NO.
4029	23-00146-00-PV	COOK	315	149
CONTRACT NO. 61M26				
ILLINOIS FED. AID PROJECT				

MODEL: Braintree - Plan 3 [Sheet]
FILE NAME: c:\bms\city\kch-pw\patro.kravets\dd140568\3983 PKM Sheets.dgn

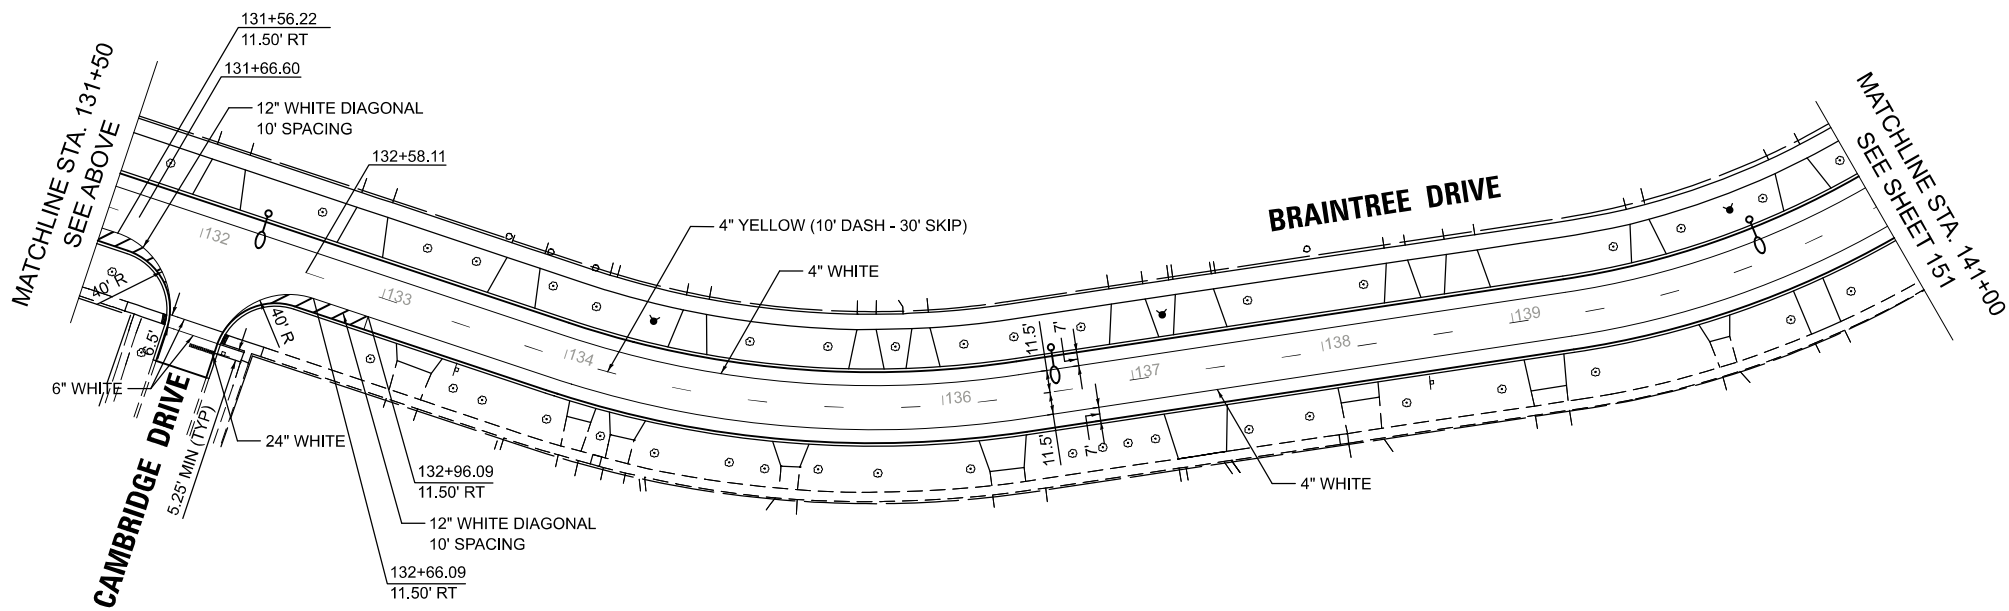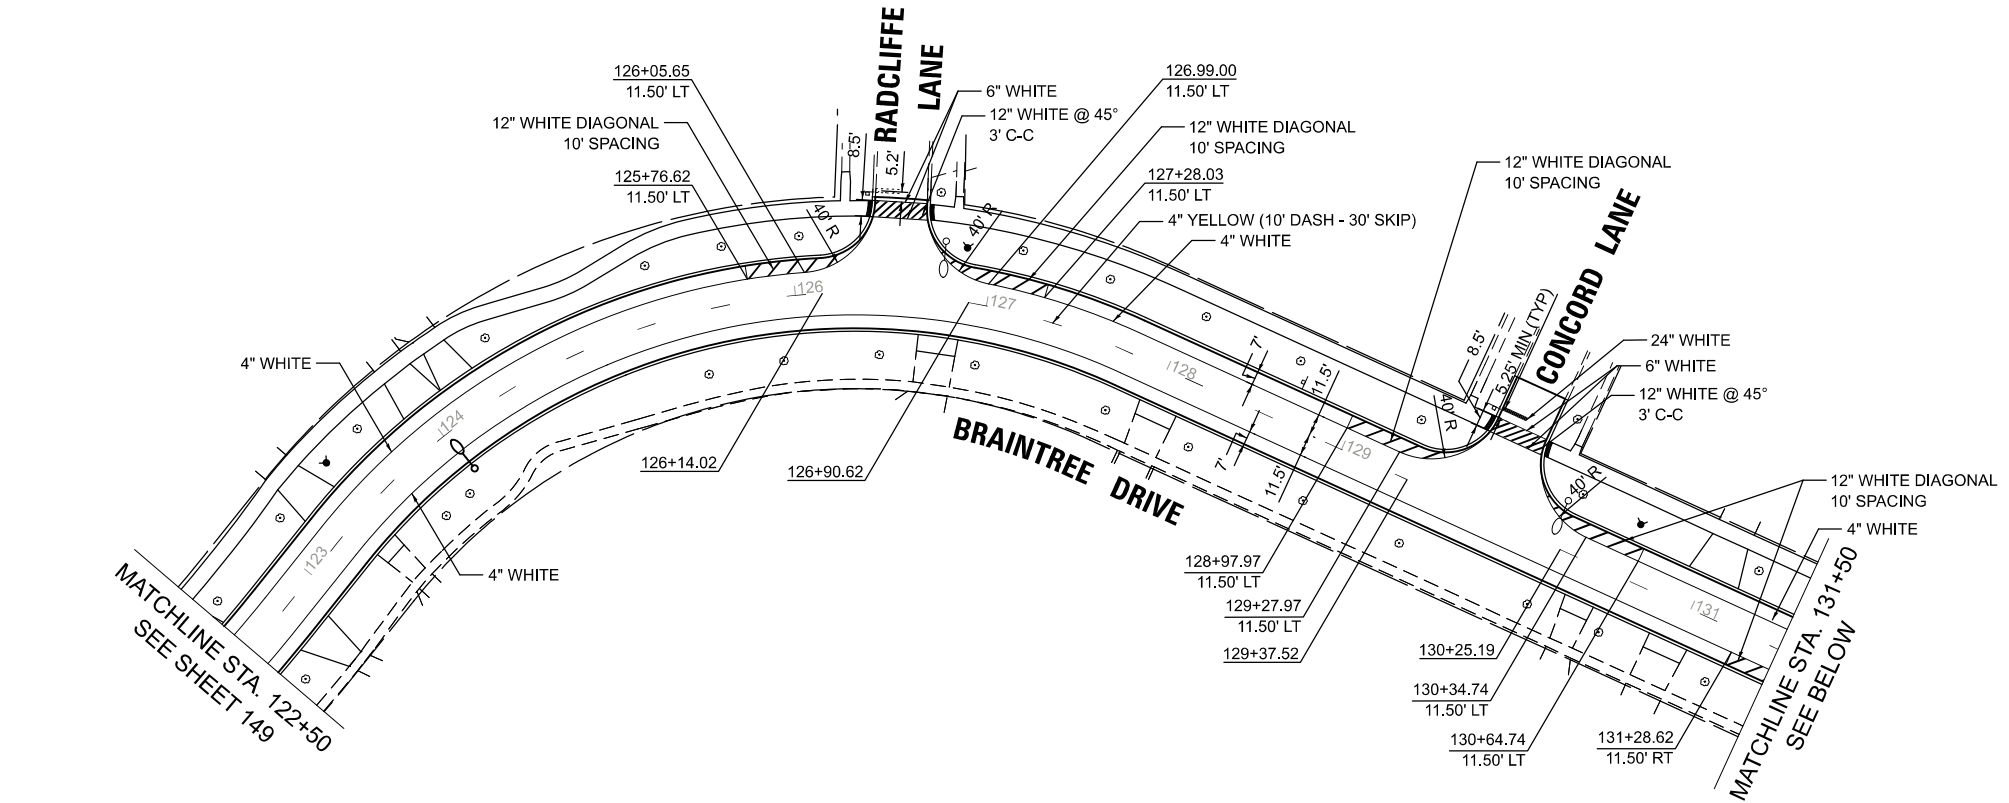


PLOT DATE	= 12/15/2025	USER NAME	= pk	DESIGNED	- AMP	REVISED	-
		DRAWN	- AMP	REVISED	-		
		CHECKED	- PK	REVISED	-		
		DATE	- 12/12/2025	REVISED	-		

STATE OF ILLINOIS
DEPARTMENT OF TRANSPORTATION

BRAINTREE DRIVE
PAVEMENT MARKING PLAN

SCALE: 1"=50'
SHEET 2 OF 4 SHEETS
STA. 122+50.00 TO STA. 141+00.00

MUN. RTE.	SECTION	COUNTY	TOTAL SHEETS	SHEET NO.
4029	23-00146-00-PV	COOK	315	150
CONTRACT NO. 61M26				
ILLINOIS FED. AID PROJECT				

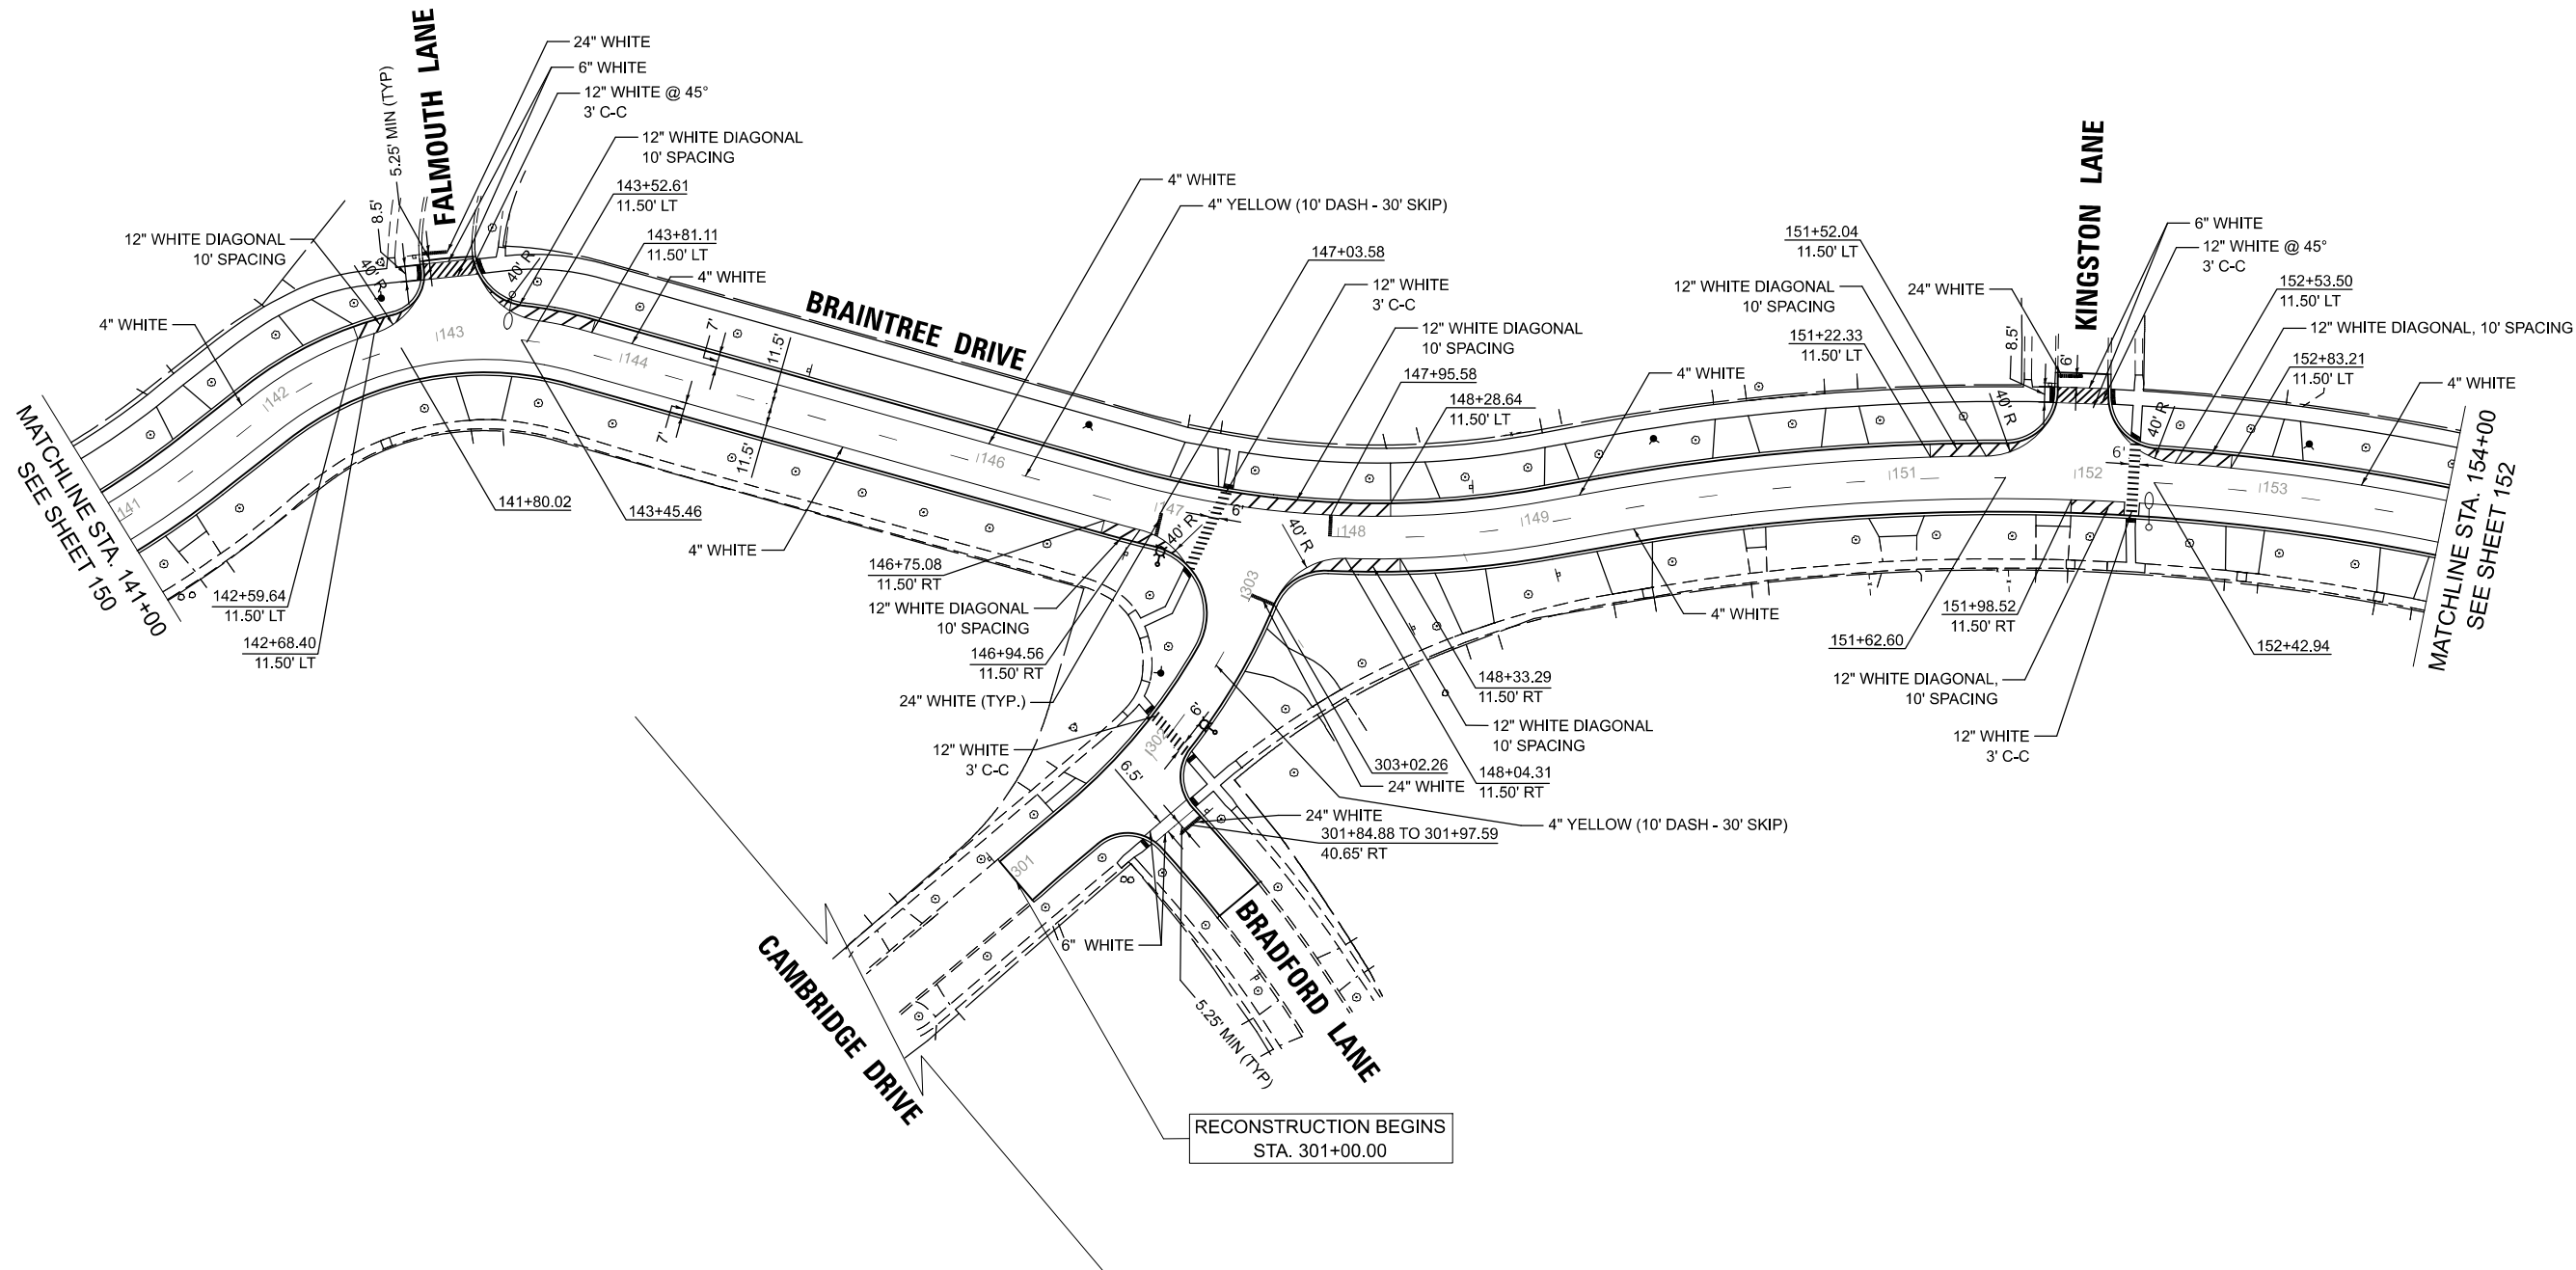

MODEL: Braintree-1 - Plan 5 [Sheet]
FILE NAME: c:\bms\stl\tech-pw\patro.kravets\dd140568\3983 PKM Sheets.dgn

PLOT DATE = 12/11/2025	USER NAME = pk	DESIGNED - AMP	REVISED -
		DRAWN - AMP	REVISED -
		CHECKED - PK	REVISED -
	DATE - 12/12/2025		REVISED -

STATE OF ILLINOIS
DEPARTMENT OF TRANSPORTATION

BRAINTREE DRIVE
PAVEMENT MARKING PLAN

SCALE: 1"=50' SHEET 3 OF 4 SHEETS STA. 141+00.00 TO STA. 154+00.00

MUN RTE.	SECTION	COUNTY	TOTAL SHEETS	SHEET NO.
4029	23-00146-00-PV	COOK	315	151
CONTRACT NO. 61M26				
ILLINOIS FED. AID PROJECT				

1. YIELD LINE SYMBOLS SHALL BE 24" WIDTH BY 36" HEIGHT WITH A SPACING OF 12" BETWEEN SYMBOLS AND PAID FOR AS "THERMOPLASTIC PAVEMENT MARKING - LETTERS AND SYMBOLS"
2. COORDINATE PROPOSED PAVEMENT MARKINGS WITH ADJACENT PROJECT CONTRACT 61M27



USER NAME = pk	DESIGNED - AMP	REVISED -
	DRAWN - AMP	REVISED -
	CHECKED - PK	REVISED -
PLOT DATE = 12/15/2025	DATE - 12/12/2025	REVISED -

STATE OF ILLINOIS
DEPARTMENT OF TRANSPORTATION

BRAINTREE DRIVE PAVEMENT MARKING PLAN

SCALE: 1"=50'	SHEET 4	OF 4	SHEETS	STA. 154+00.00	TO STA. 159+00.00
---------------	---------	------	--------	----------------	-------------------

MUN RTE.	SECTION	COUNTY	TOTAL SHEETS	SHEET NO.
4029	23-00146-00-PV	COOK	315	152
		CONTRACT NO. 61M26		
		ILLINOIS	FED. AID PROJECT	

MODEL: Braintree-1 - Plan 6 [Sheet]
FILE NAME: c:\bms\civiltech-pw\petro.kravets\0140568\3993 PMK Sheets.dgn

MODEL: Braintree - Plan 1 [Sheet]
FILE NAME: c:\bms\citytech-pw\patc.kravets\0140568\3983 Existing Signing Sheets.dgn

LEGEND

	EXISTING LIGHT POLE
	EXISTING SIGN
	PROPOSED SIGN PANEL, TYPE 1 OR TYPE 2
REMAIN	SIGN PANEL TO REMAIN IN SAME LOCATION
RELOCATE	SIGN PANEL TO BE RELOCATED TO NEW POST
	REMOVE SIGN PANEL ASSEMBLY

USER NAME	= pk
DESIGNED	- AMP
DRAWN	- AMP
CHECKED	- PK
PLOT DATE	= 12/15/2025
DATE	- 12/12/2025



REVISED	-
REVISED	-
REVISED	-
REVISED	-

STATE OF ILLINOIS
DEPARTMENT OF TRANSPORTATION

BRAINTREE DRIVE EXISTING SIGNING PLAN

SCALE: 1"=50'
SHEET 1 OF 4 SHEETS
STA. 100+00.00 TO STA. 122+50.00



MUN. RTE.	SECTION	COUNTY	TOTAL SHEETS	SHEET NO.
4029	23-00146-00-PV	COOK	315	153
CONTRACT NO. 61M26				
ILLINOIS FED. AID PROJECT				

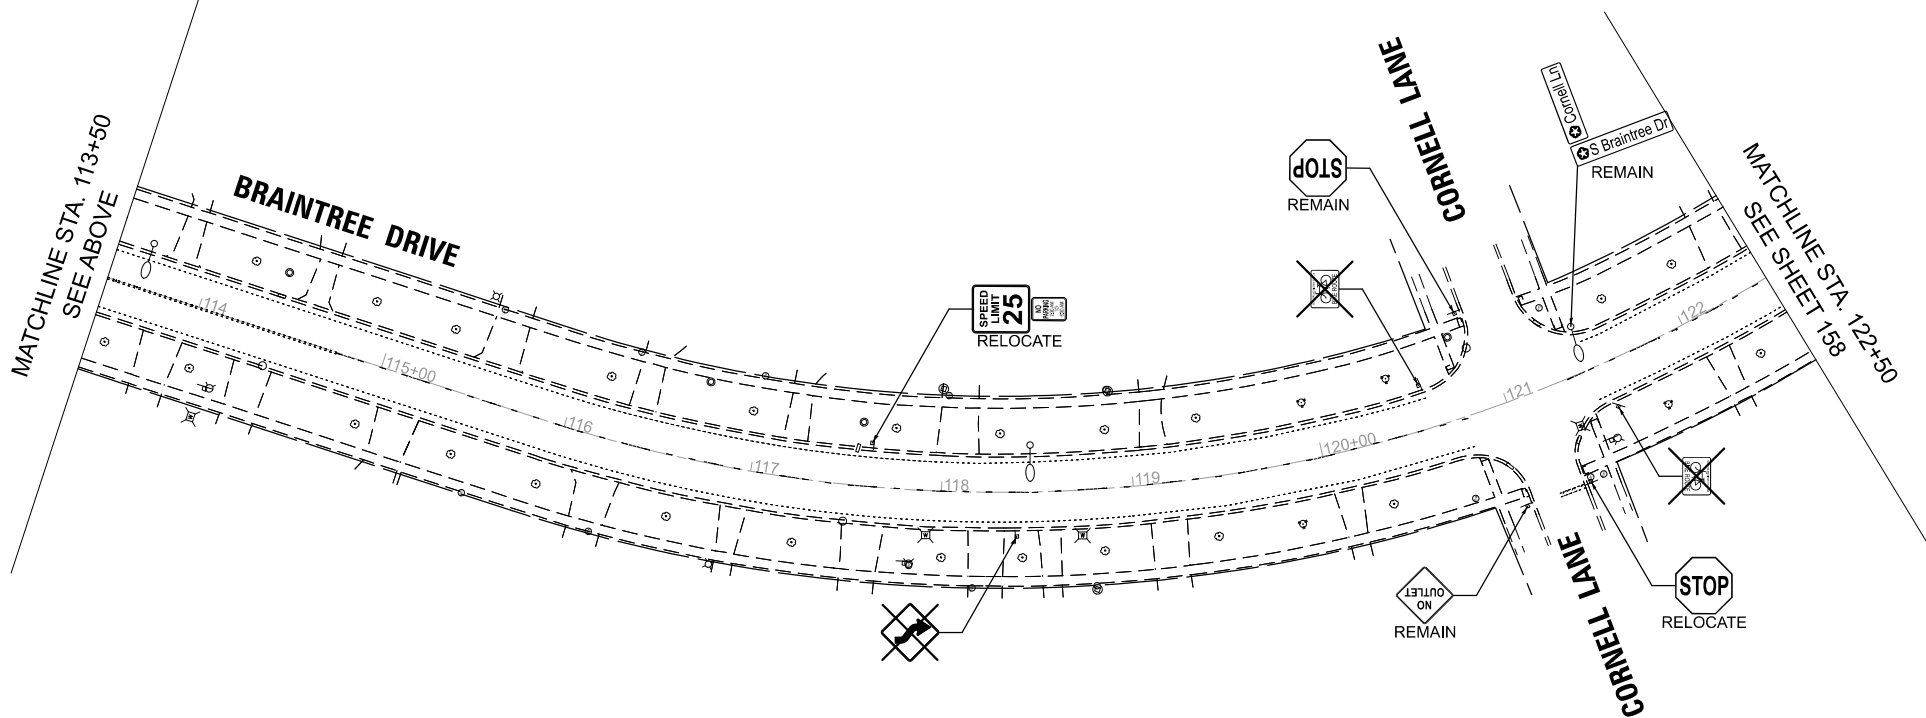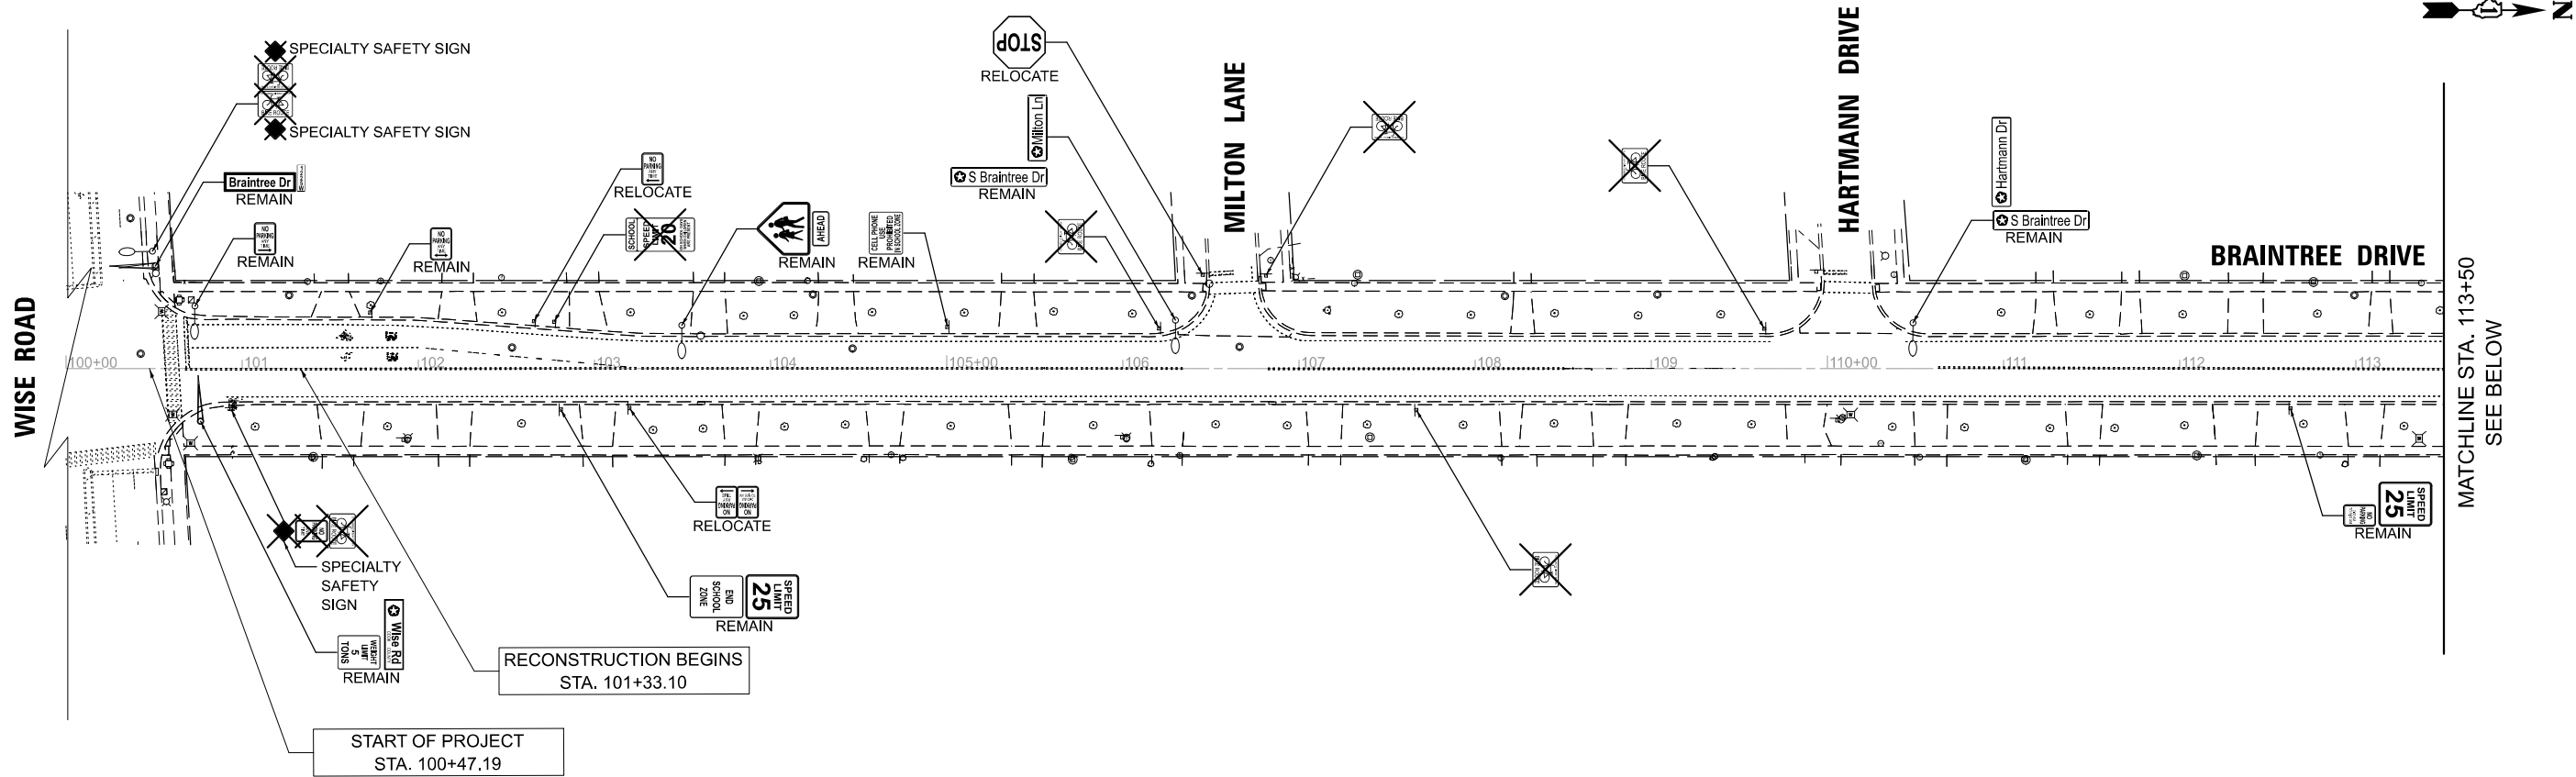

MODEL: Braintree - Plan 3 [Sheet]
FILE NAME: c:\bms\city\tech-pw\patro.kravets\0140568\3983 Existing Signing Sheets.dgn

LEGEND

-  EXISTING LIGHT POLE
-  EXISTING SIGN
-  PROPOSED SIGN PANEL, TYPE 1 OR TYPE 2
-  REMAIN
-  SIGN PANEL TO REMAIN IN SAME LOCATION
-  SIGN PANEL TO BE RELOCATED TO NEW POST
-  REMOVE SIGN PANEL ASSEMBLY

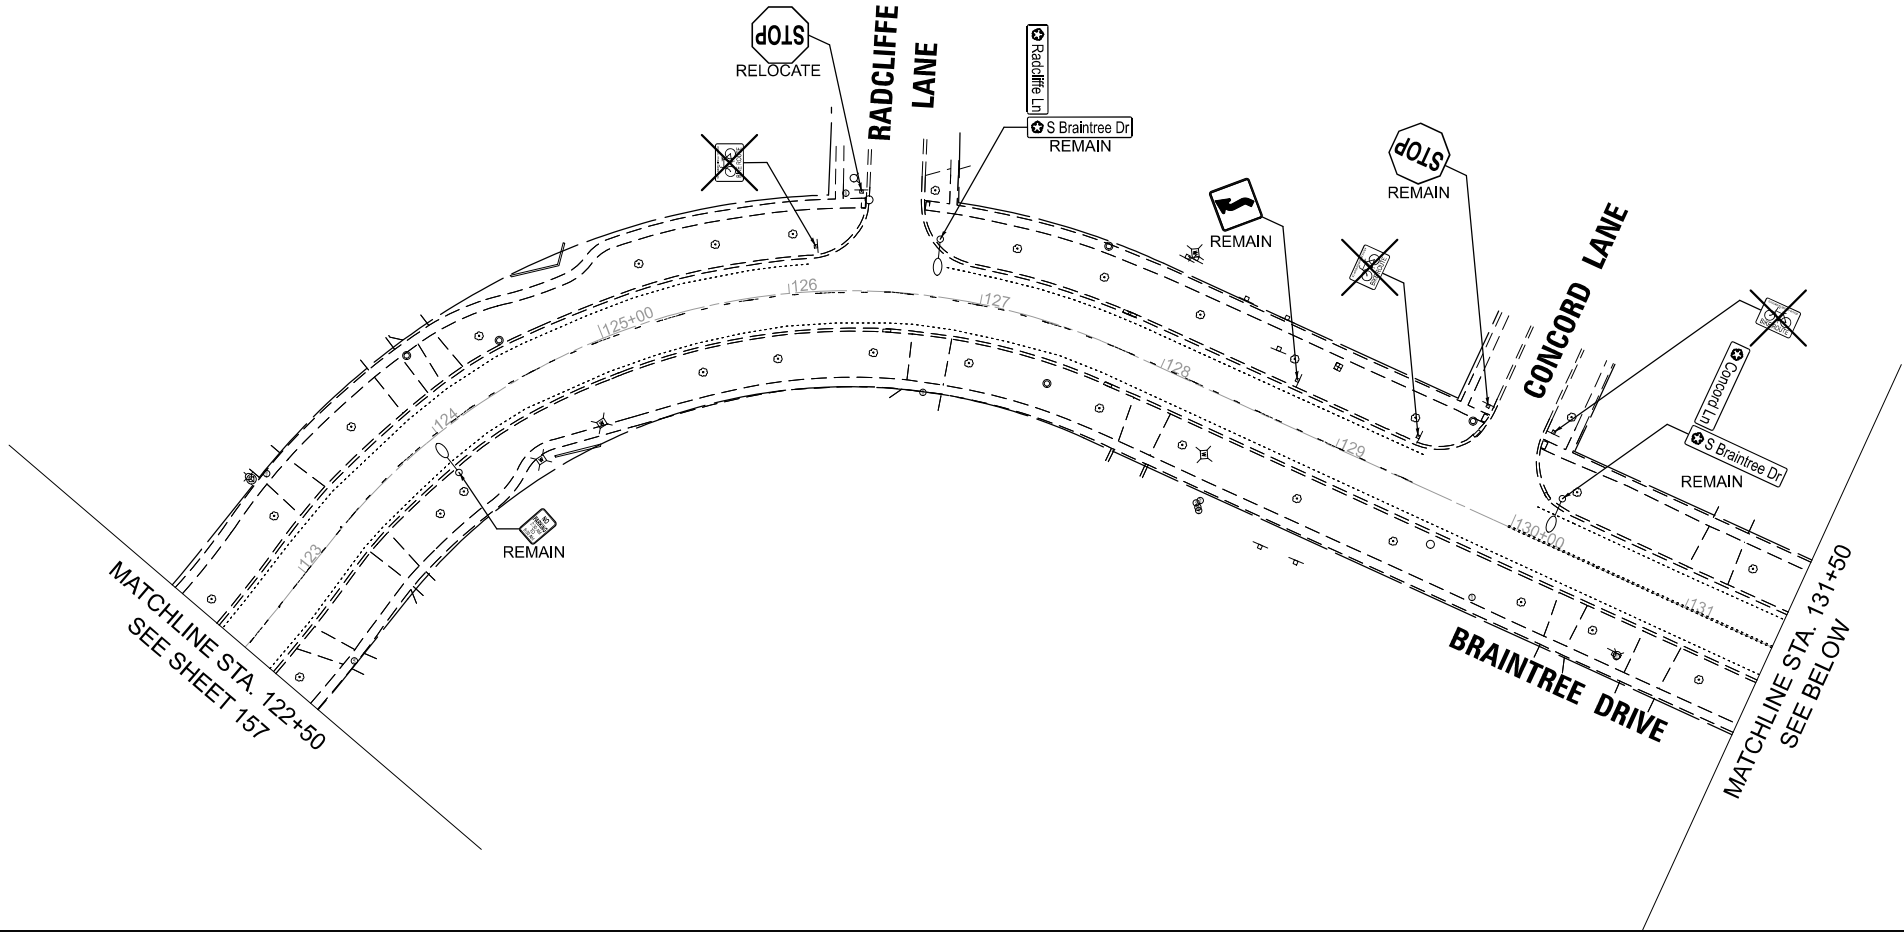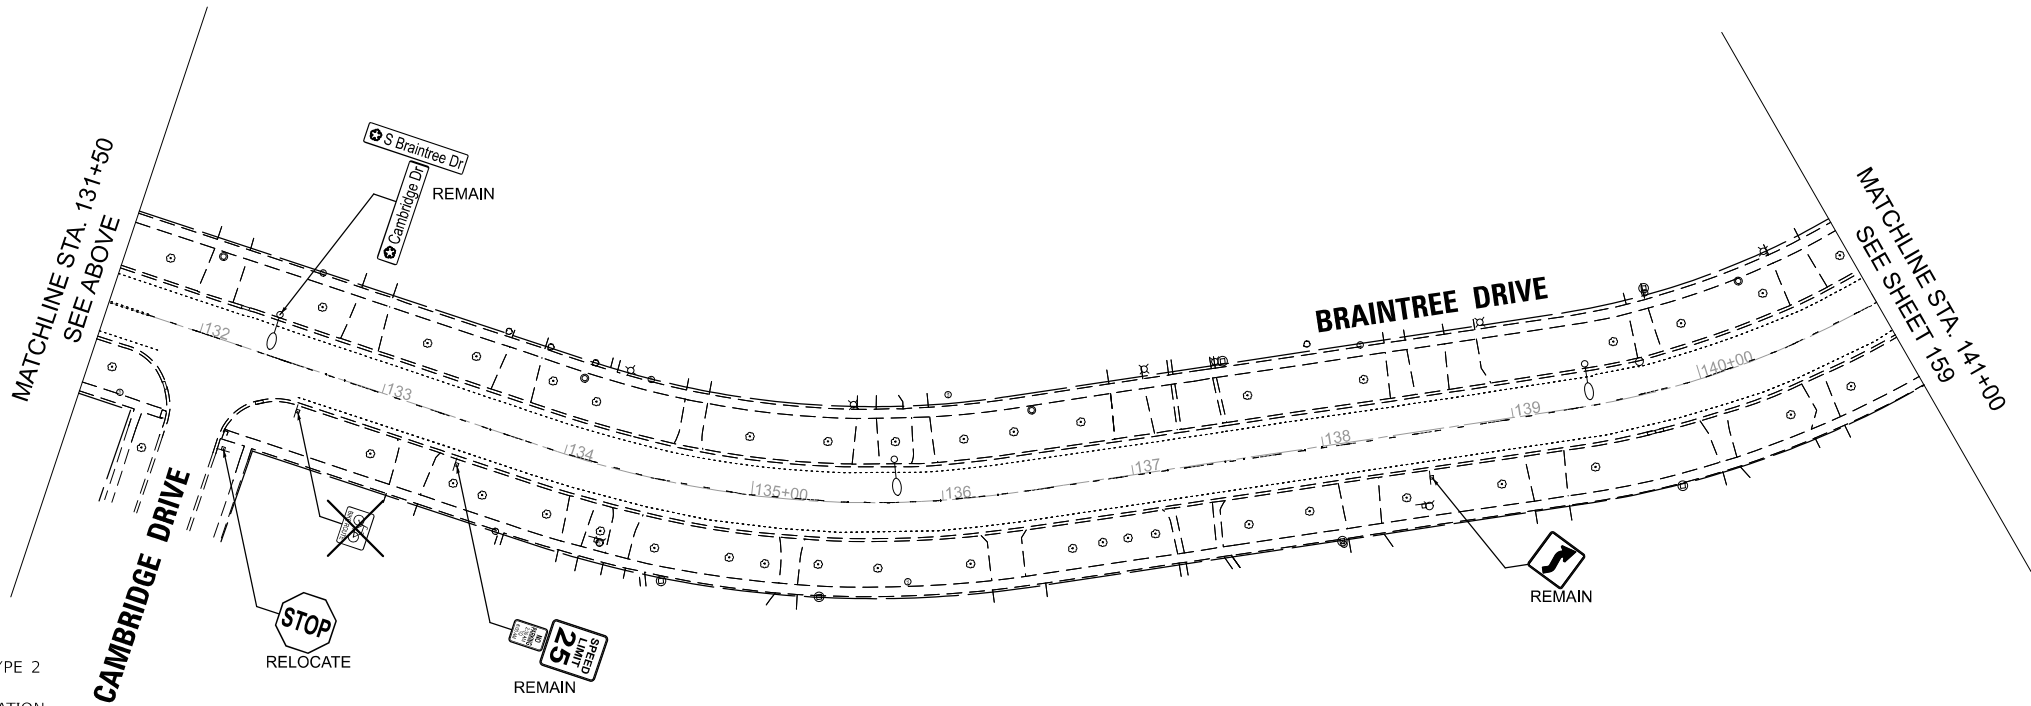


STATE OF ILLINOIS
DEPARTMENT OF TRANSPORTATION

BRAINTREE DRIVE
EXISTING SIGNING PLAN

SCALE: 1"=50' SHEET 2 OF 4 SHEETS STA. 122+50.00 TO STA. 141+00.00

MUN RTE.	SECTION	COUNTY	TOTAL SHEETS	SHEET NO.
4029	23-00146-00-PV	COOK	315	154
CONTRACT NO. 61M26				
ILLINOIS FED. AID PROJECT				

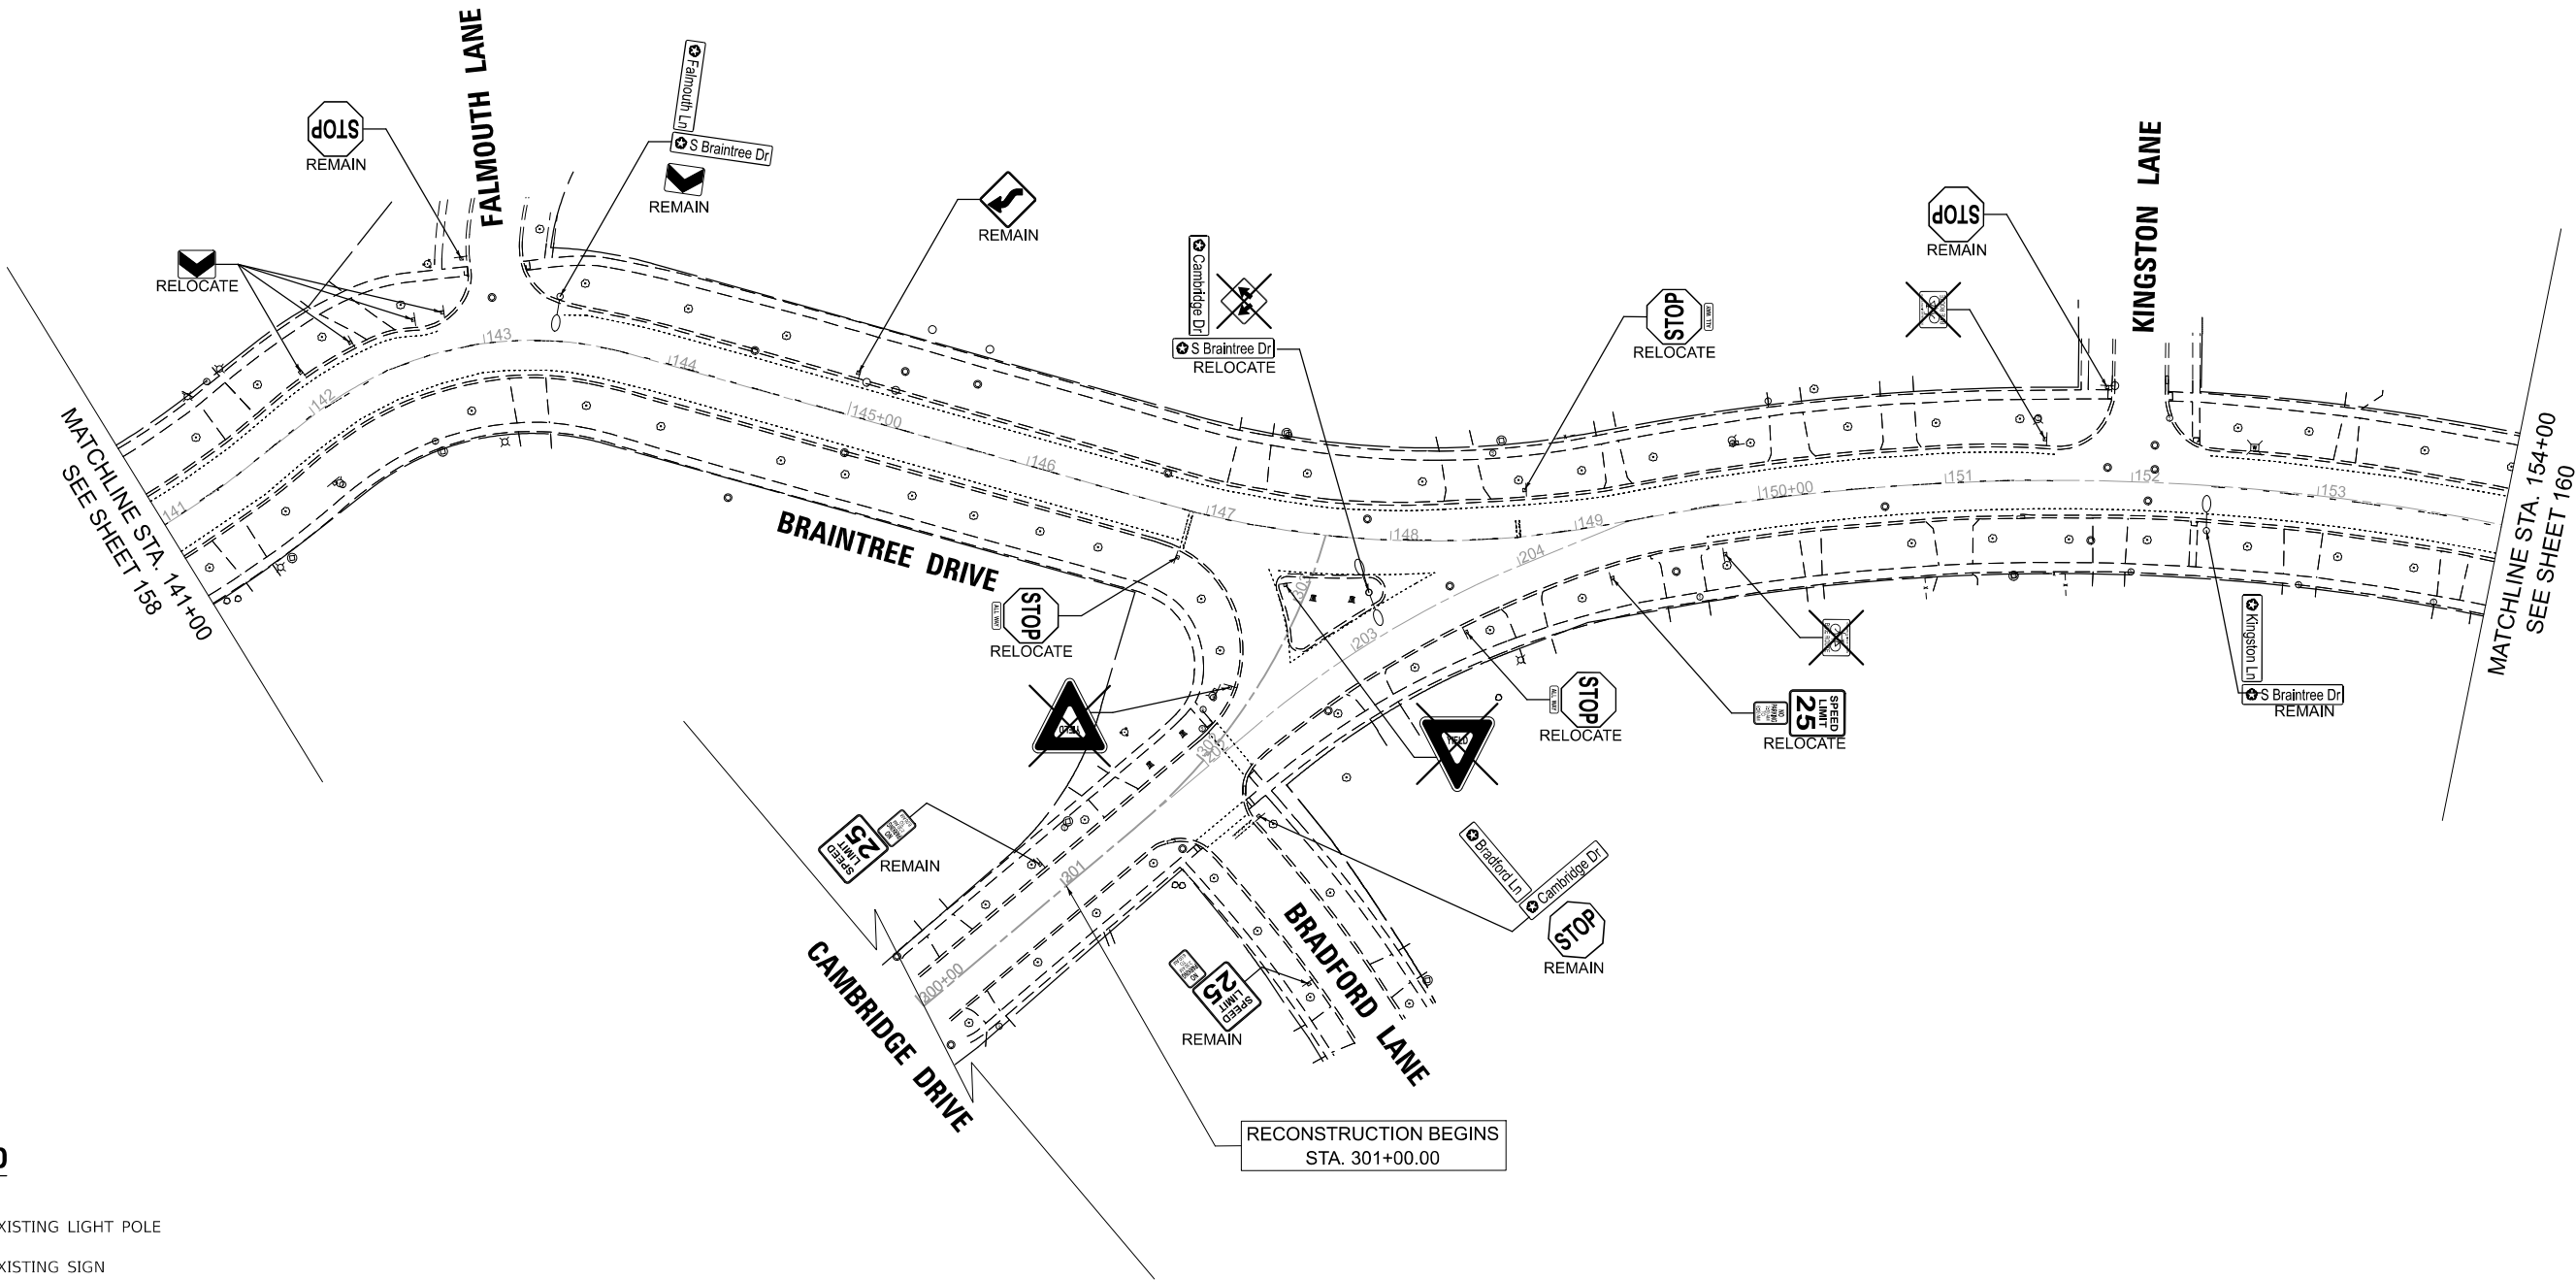


LEGEND

- EXISTING LIGHT POLE
- EXISTING SIGN
- PROPOSED SIGN PANEL, TYPE 1 OR TYPE 2
- SIGN PANEL TO REMAIN IN SAME LOCATION
- SIGN PANEL TO BE RELOCATED TO NEW POST
- REMOVE SIGN PANEL ASSEMBLY

MODEL: Braintree-1 - Plan 5 [Sheet]
FILE NAME: c:\bms\stl\tech-pw\patro.kravets\0140568\3983 Existing Signing Sheets.dgn

	USER NAME = pk		DESIGNED - AMP	REVISED -	STATE OF ILLINOIS DEPARTMENT OF TRANSPORTATION	BRAINTREE DRIVE EXISTING SIGNING PLAN			MUN RTE.	SECTION	COUNTY	TOTAL SHEETS	SHEET NO.
			DRAWN - AMP	REVISED -					4029	23-00146-00-PV	COOK	315	155
			CHECKED - PK	REVISED -					CONTRACT NO. 61M26				
	PLOT DATE = 12/15/2025		DATE - 12/12/2025	REVISED -		SCALE: 1"=50'	SHEET 3	OF 4 SHEETS	STA. 141+00.00	TO STA. 154+00.00	ILLINOIS FED. AID PROJECT		

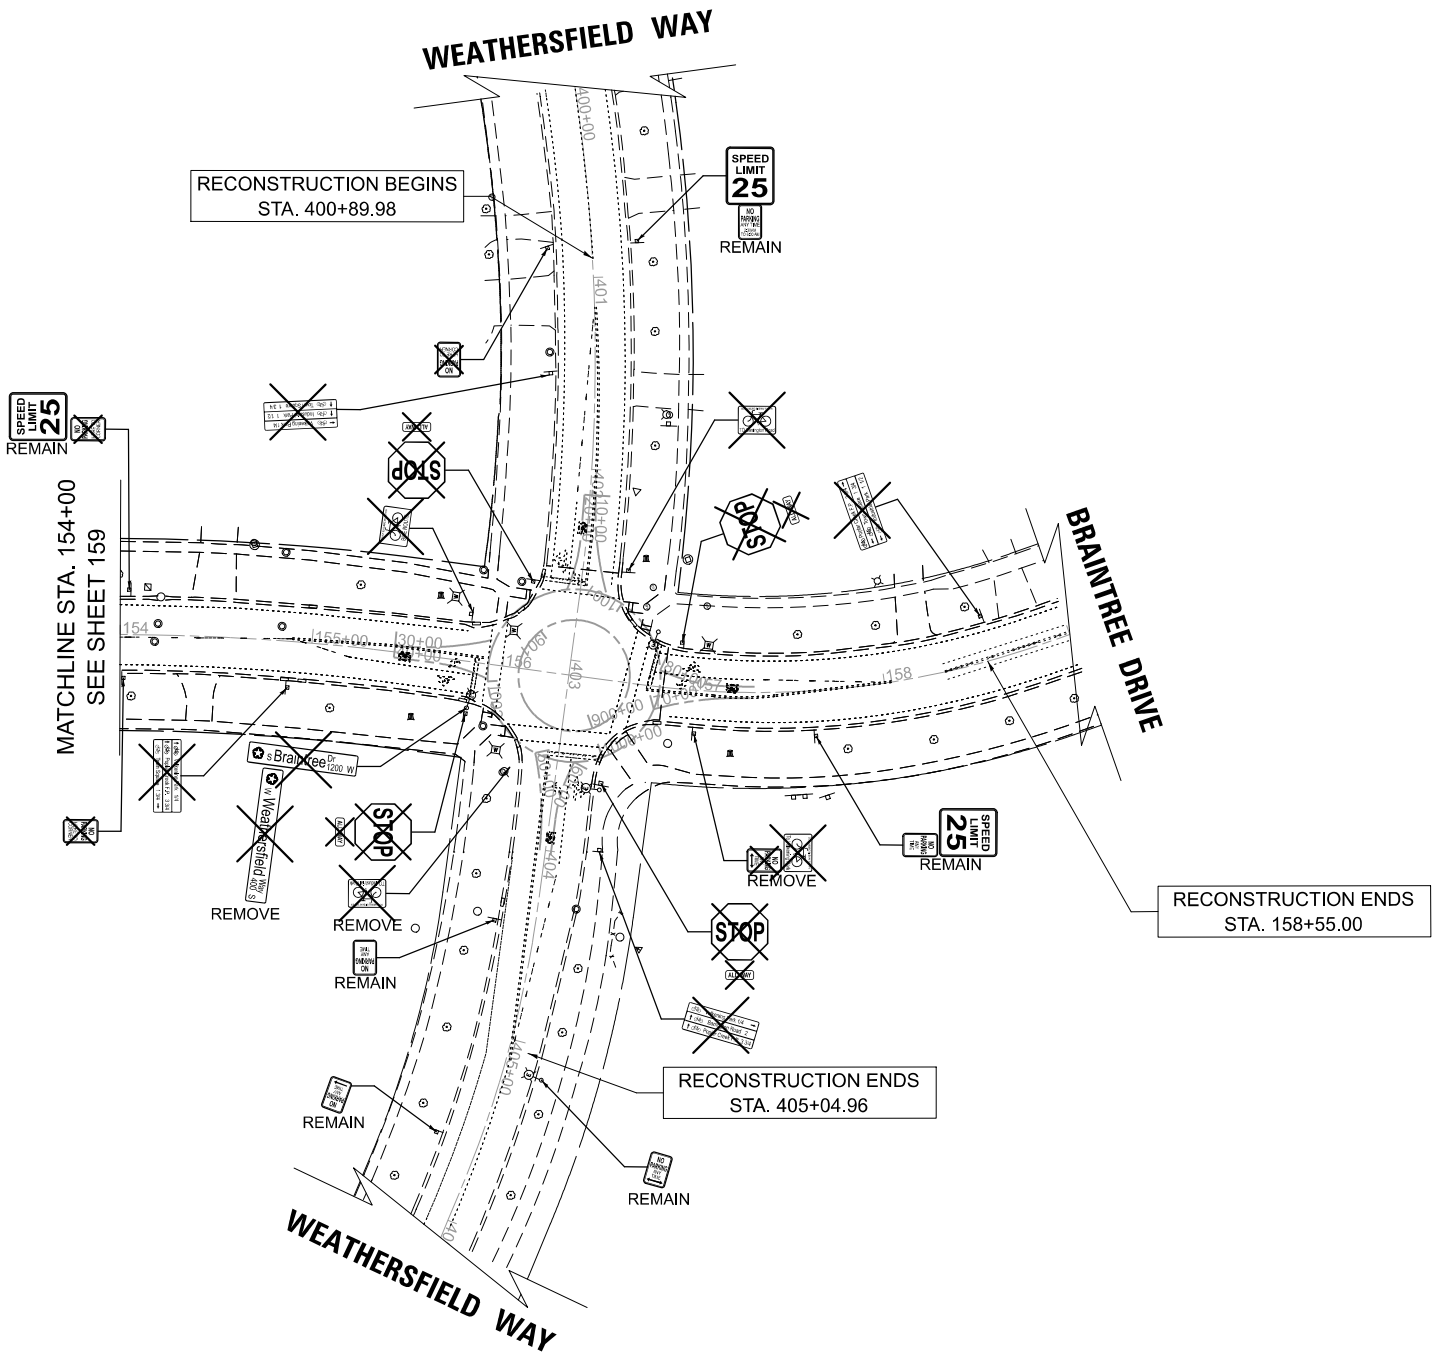

LEGEND

-  EXISTING LIGHT POLE
-  EXISTING SIGN
-  PROPOSED SIGN PANEL, TYPE 1 OR TYPE 2
-  SIGN PANEL TO REMAIN IN SAME LOCATION
-  SIGN PANEL TO BE RELOCATED TO NEW POST
-  REMOVE SIGN PANEL ASSEMBLY

MODEL: Braintree-1 - Plan 6 [Sheet]
FILE NAME: c:\bms\stl\sch-pv\pairo.kravets\0140568\3983 Existing Signing Sheets.dgn



	USER NAME = pk	DESIGNED - AMP	REVISED -
		DRAWN - AMP	REVISED -
		CHECKED - PK	REVISED -
	PLOT DATE = 12/11/2025	DATE - 12/12/2025	REVISED -

STATE OF ILLINOIS
DEPARTMENT OF TRANSPORTATION

**BRAINTREE DRIVE
EXISTING SIGNING PLAN**


SCALE: 1"=50' SHEET 4 OF 4 SHEETS STA. 154+00.00 TO STA. 159+00.00

MUN. RTE.	SECTION	COUNTY	TOTAL SHEETS	SHEET NO.
4029	23-00146-00-PV	COOK	315	156
CONTRACT NO. 61M26				
ILLINOIS FED. AID PROJECT				

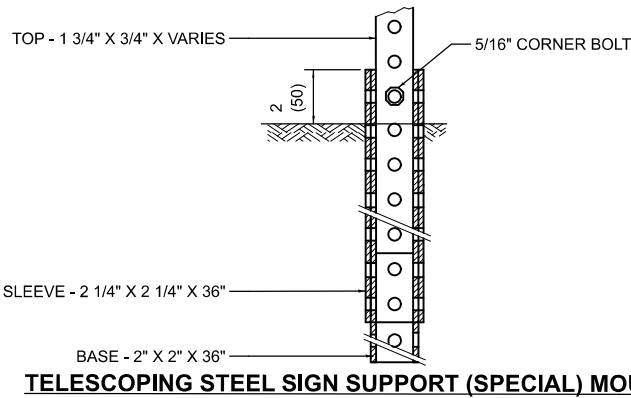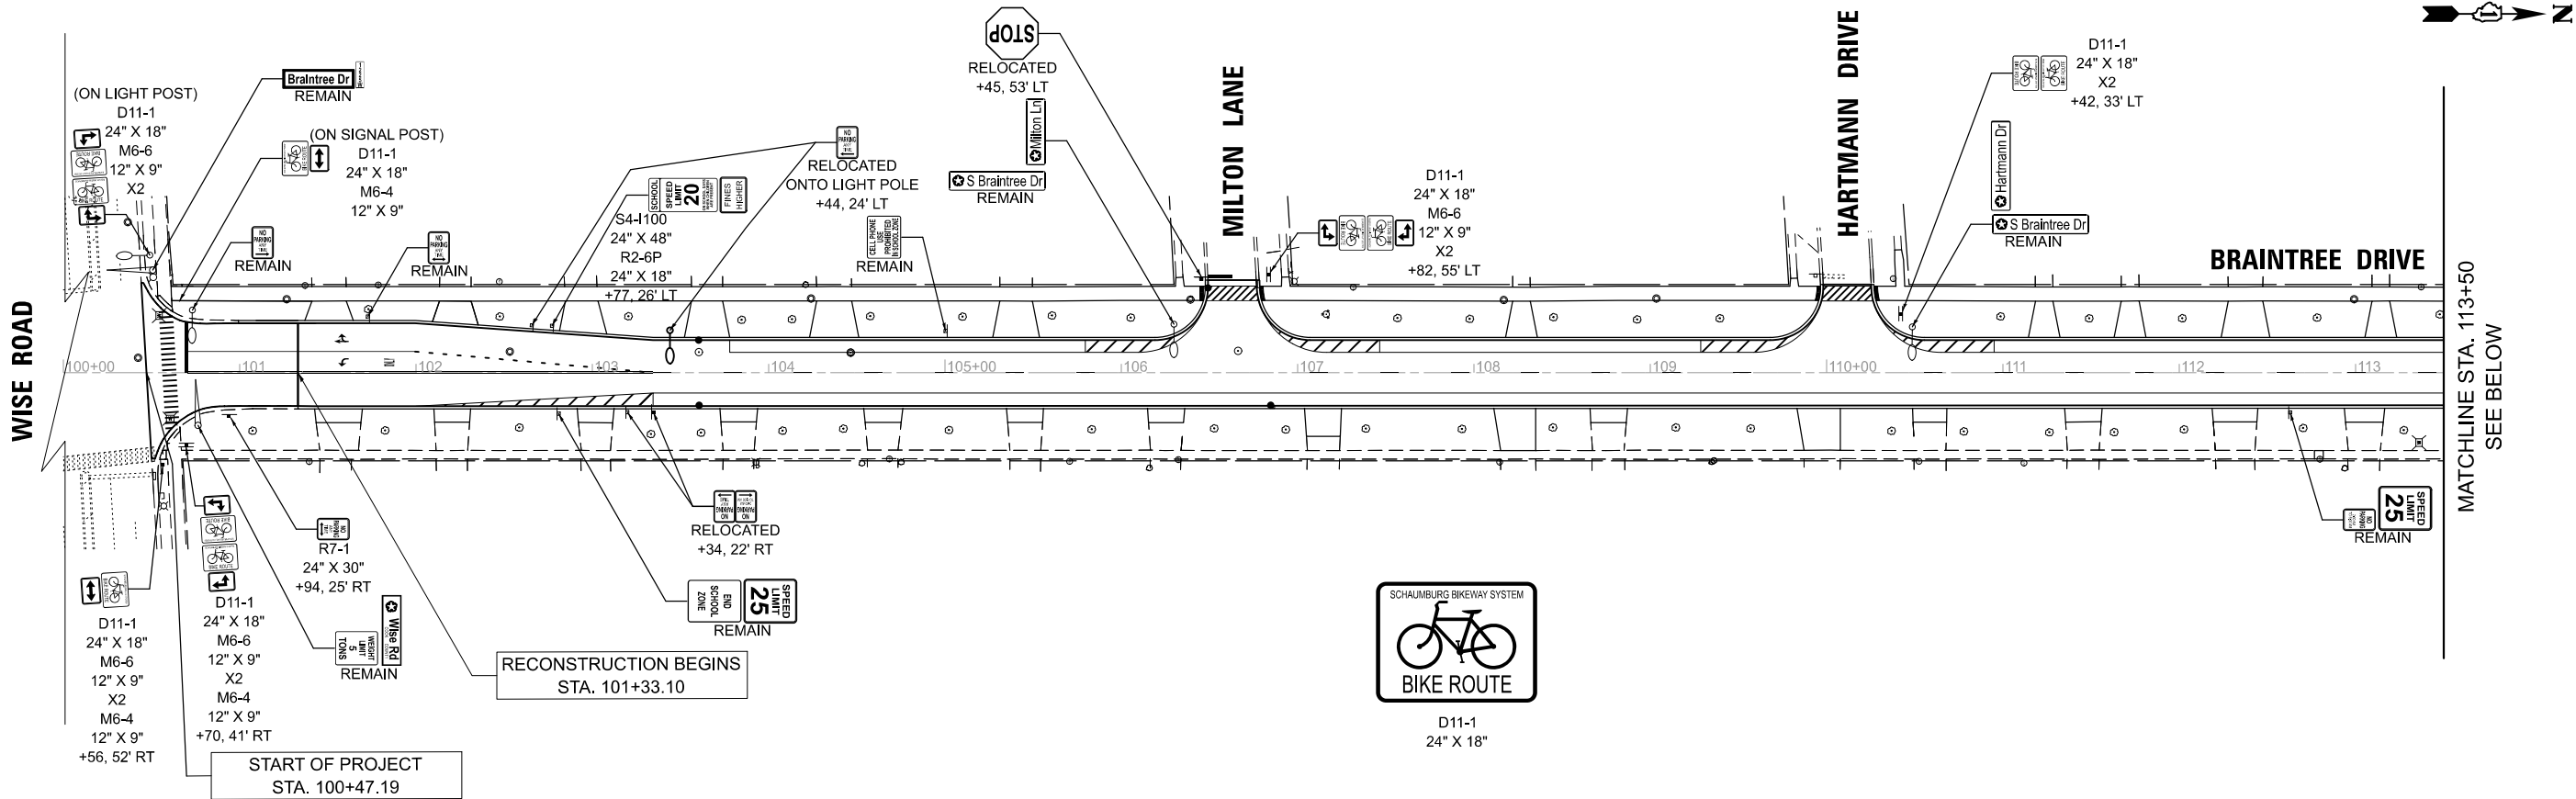

LEGEND

- EXISTING LIGHT POLE
- PROPOSED LIGHT POLE
- EXISTING SIGN TO REMAIN
- PROPOSED SIGN PANEL, TYPE 1 (SPECIAL) OR TYPE 2 (SPECIAL)
- REMAIN: SIGN PANEL TO REMAIN IN SAME LOCATION
- RELOCATED: SIGN PANEL TO BE RELOCATED

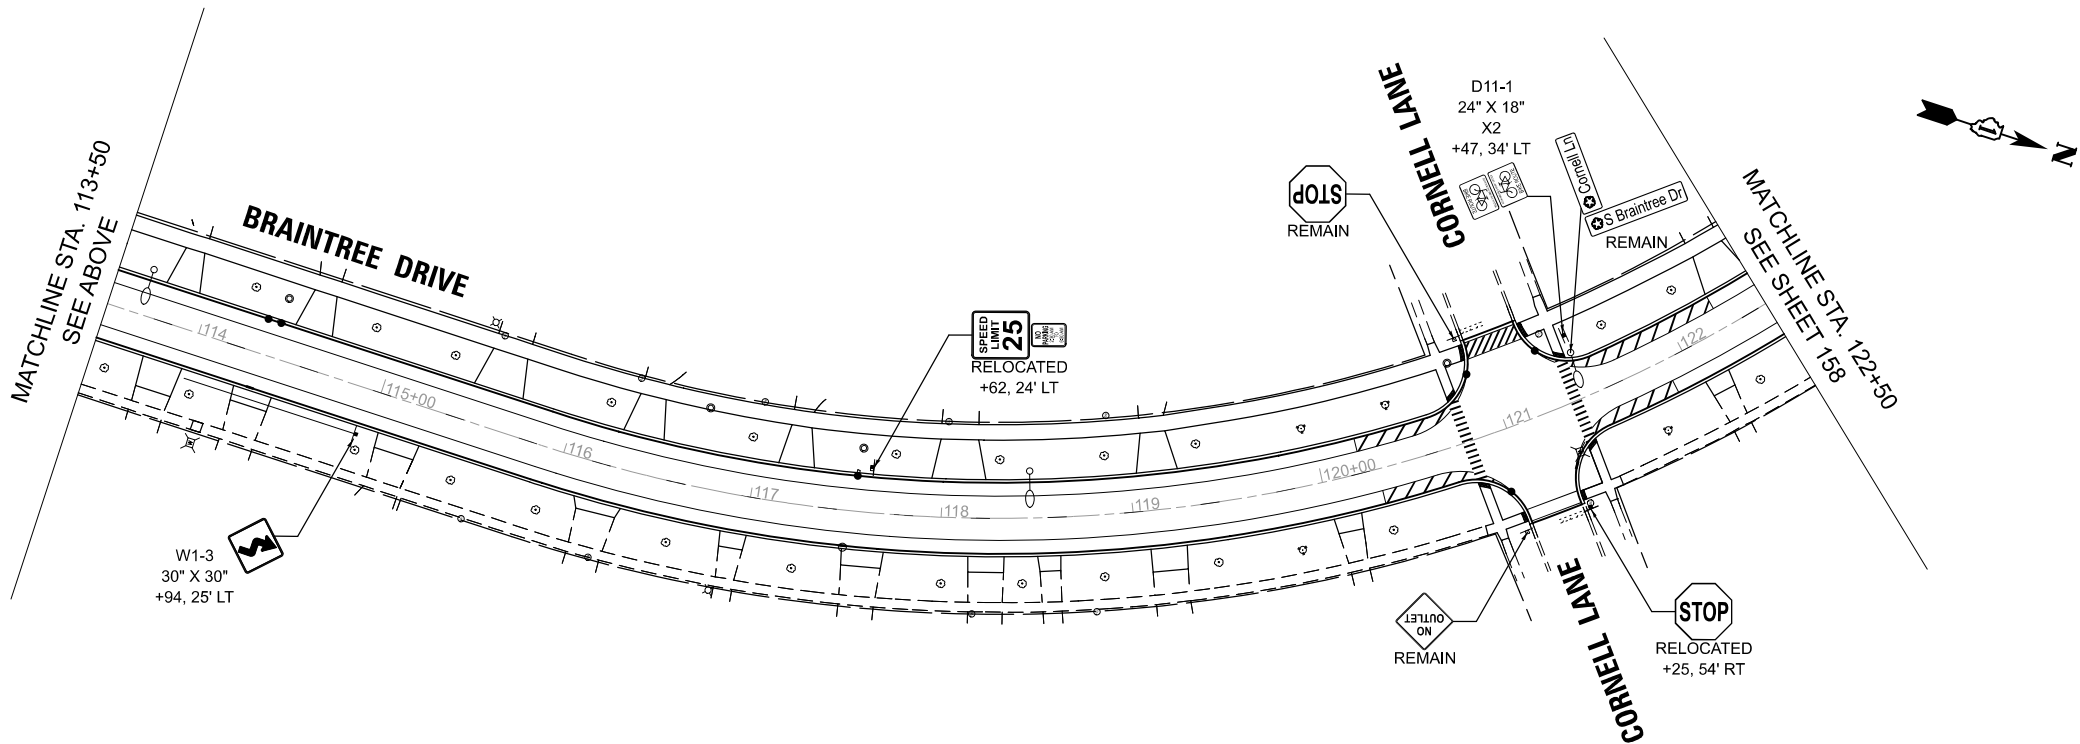

MODEL: Braintree - Plan 1 [Sheet]
FILE NAME: c:\bms\sketch\p\patro.kravets\0140568\3993 Proposed Signing Sheets.dgn

PLOT DATE = 12/15/2025	USER NAME = pk	DESIGNED - AMP	REVISED -
		DRAWN - AMP	REVISED -
		CHECKED - PK	REVISED -
	DATE - 12/12/2025		REVISED -

STATE OF ILLINOIS
DEPARTMENT OF TRANSPORTATION

BRAINTREE DRIVE
PROPOSED SIGNING PLAN

SCALE: 1"=50' SHEET 1 OF 4 SHEETS STA. 100+00.00 TO STA. 122+50.00

MUN. RTE.	SECTION	COUNTY	TOTAL SHEETS	SHEET NO.
4029	23-00146-00-PV	COOK	315	157
CONTRACT NO. 61M26				
ILLINOIS FED. AID PROJECT				

MODEL: Braintree - Plan 3 [Sheet]
FILE NAME: c:\bms\sk\litch-p\patro.kravets\0140568\3983 Proposed Signing Sheets.dgn

LEGEND

- 
- EXISTING LIGHT POLE



PROPOSED LIGHT POLE

EXISTING SIGN TO REMAIN

PROPOSED SIGN PANEL, TYPE 1 (SPECIAL) OR TYPE 2 (SPECIAL)
- REMAIN

RELOCATED
- SIGN PANEL TO REMAIN IN SAME LOCATION

SIGN PANEL TO BE RELOCATED

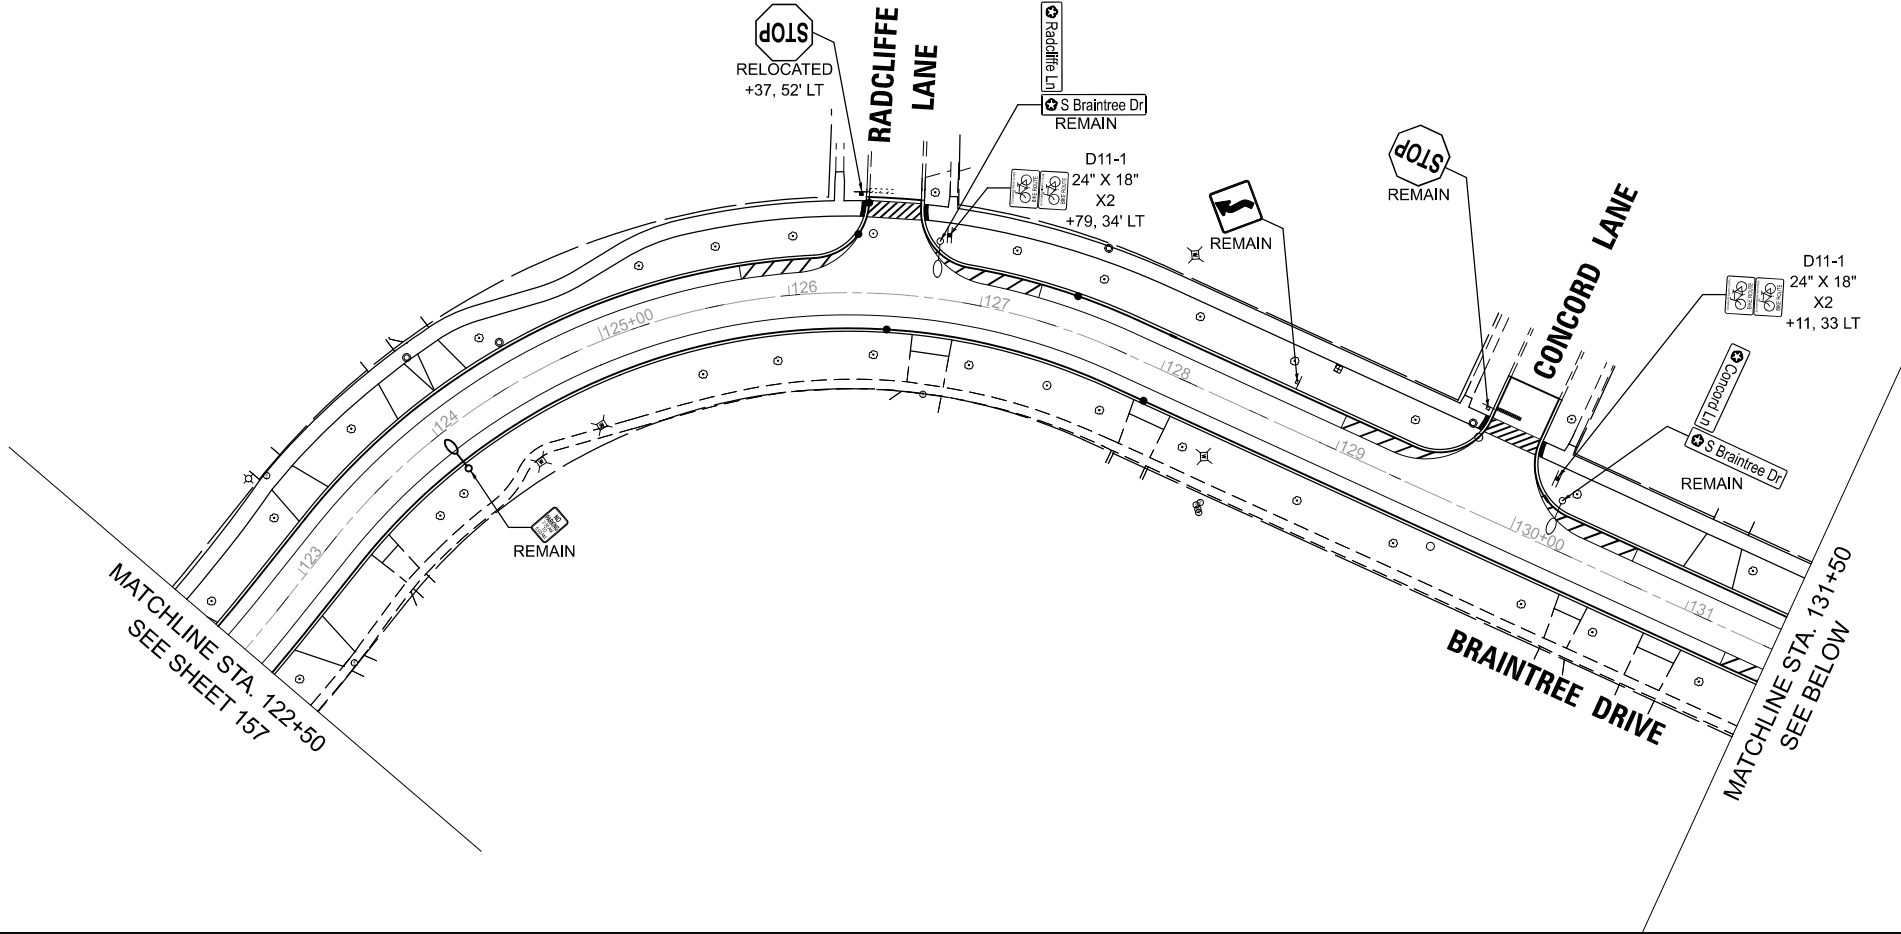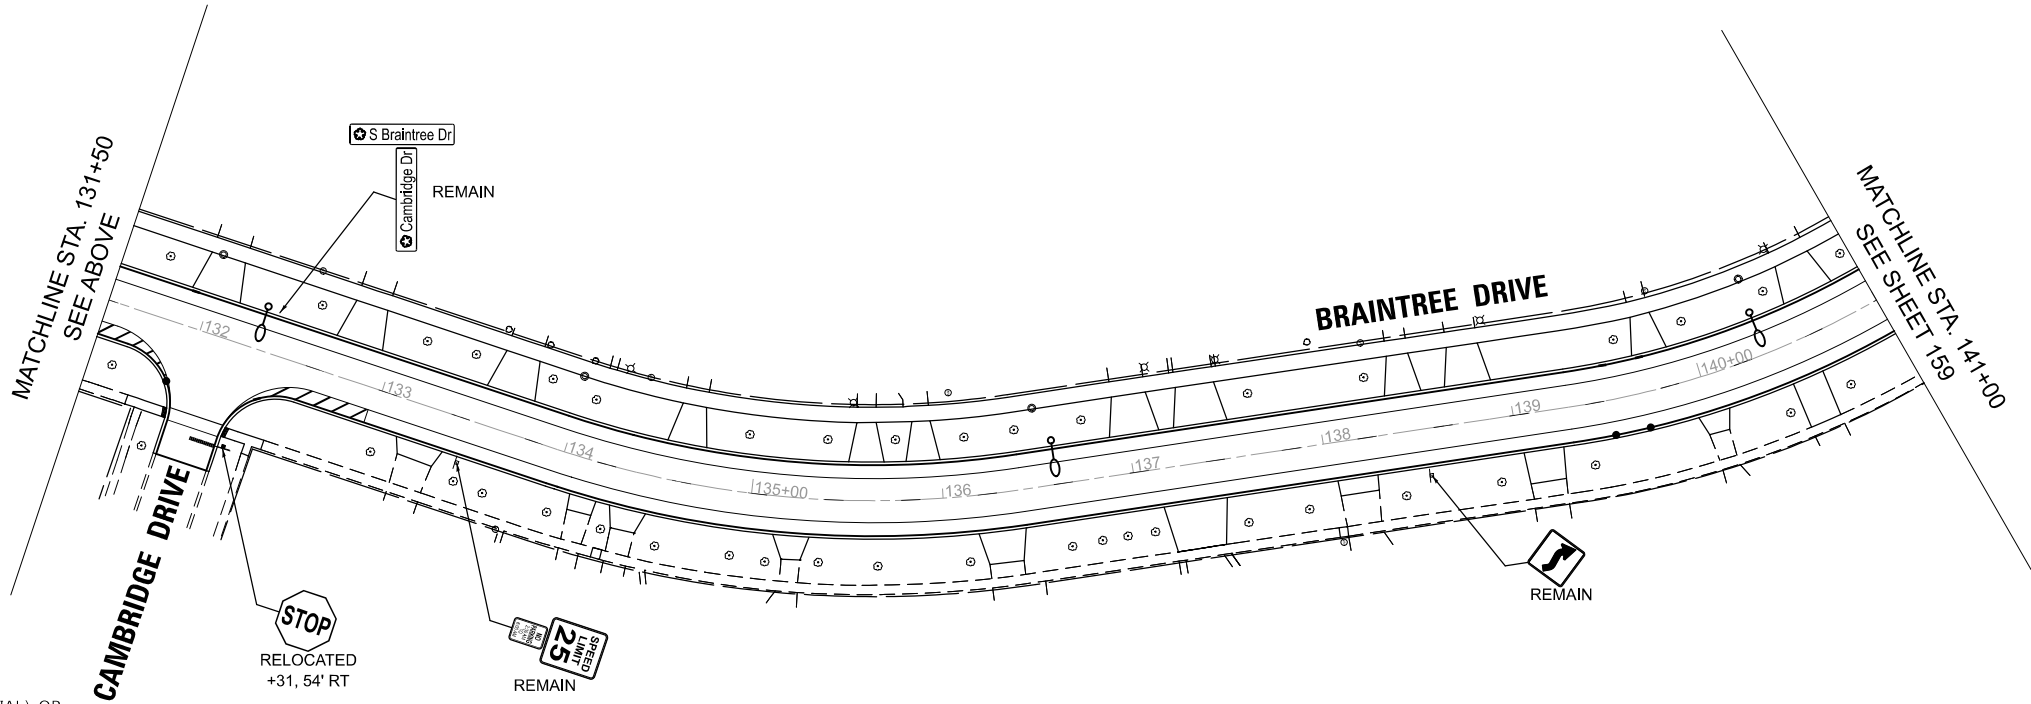


STATE OF ILLINOIS
DEPARTMENT OF TRANSPORTATION

BRAINTREE DRIVE
PROPOSED SIGNING PLAN

SCALE: 1"=50' SHEET 2 OF 4 SHEETS STA. 122+50.00 TO STA. 141+00.00

MUN RTE.	SECTION	COUNTY	TOTAL SHEETS	SHEET NO.
4029	23-00146-00-PV	COOK	315	158
CONTRACT NO. 61M26				
ILLINOIS FED. AID PROJECT				

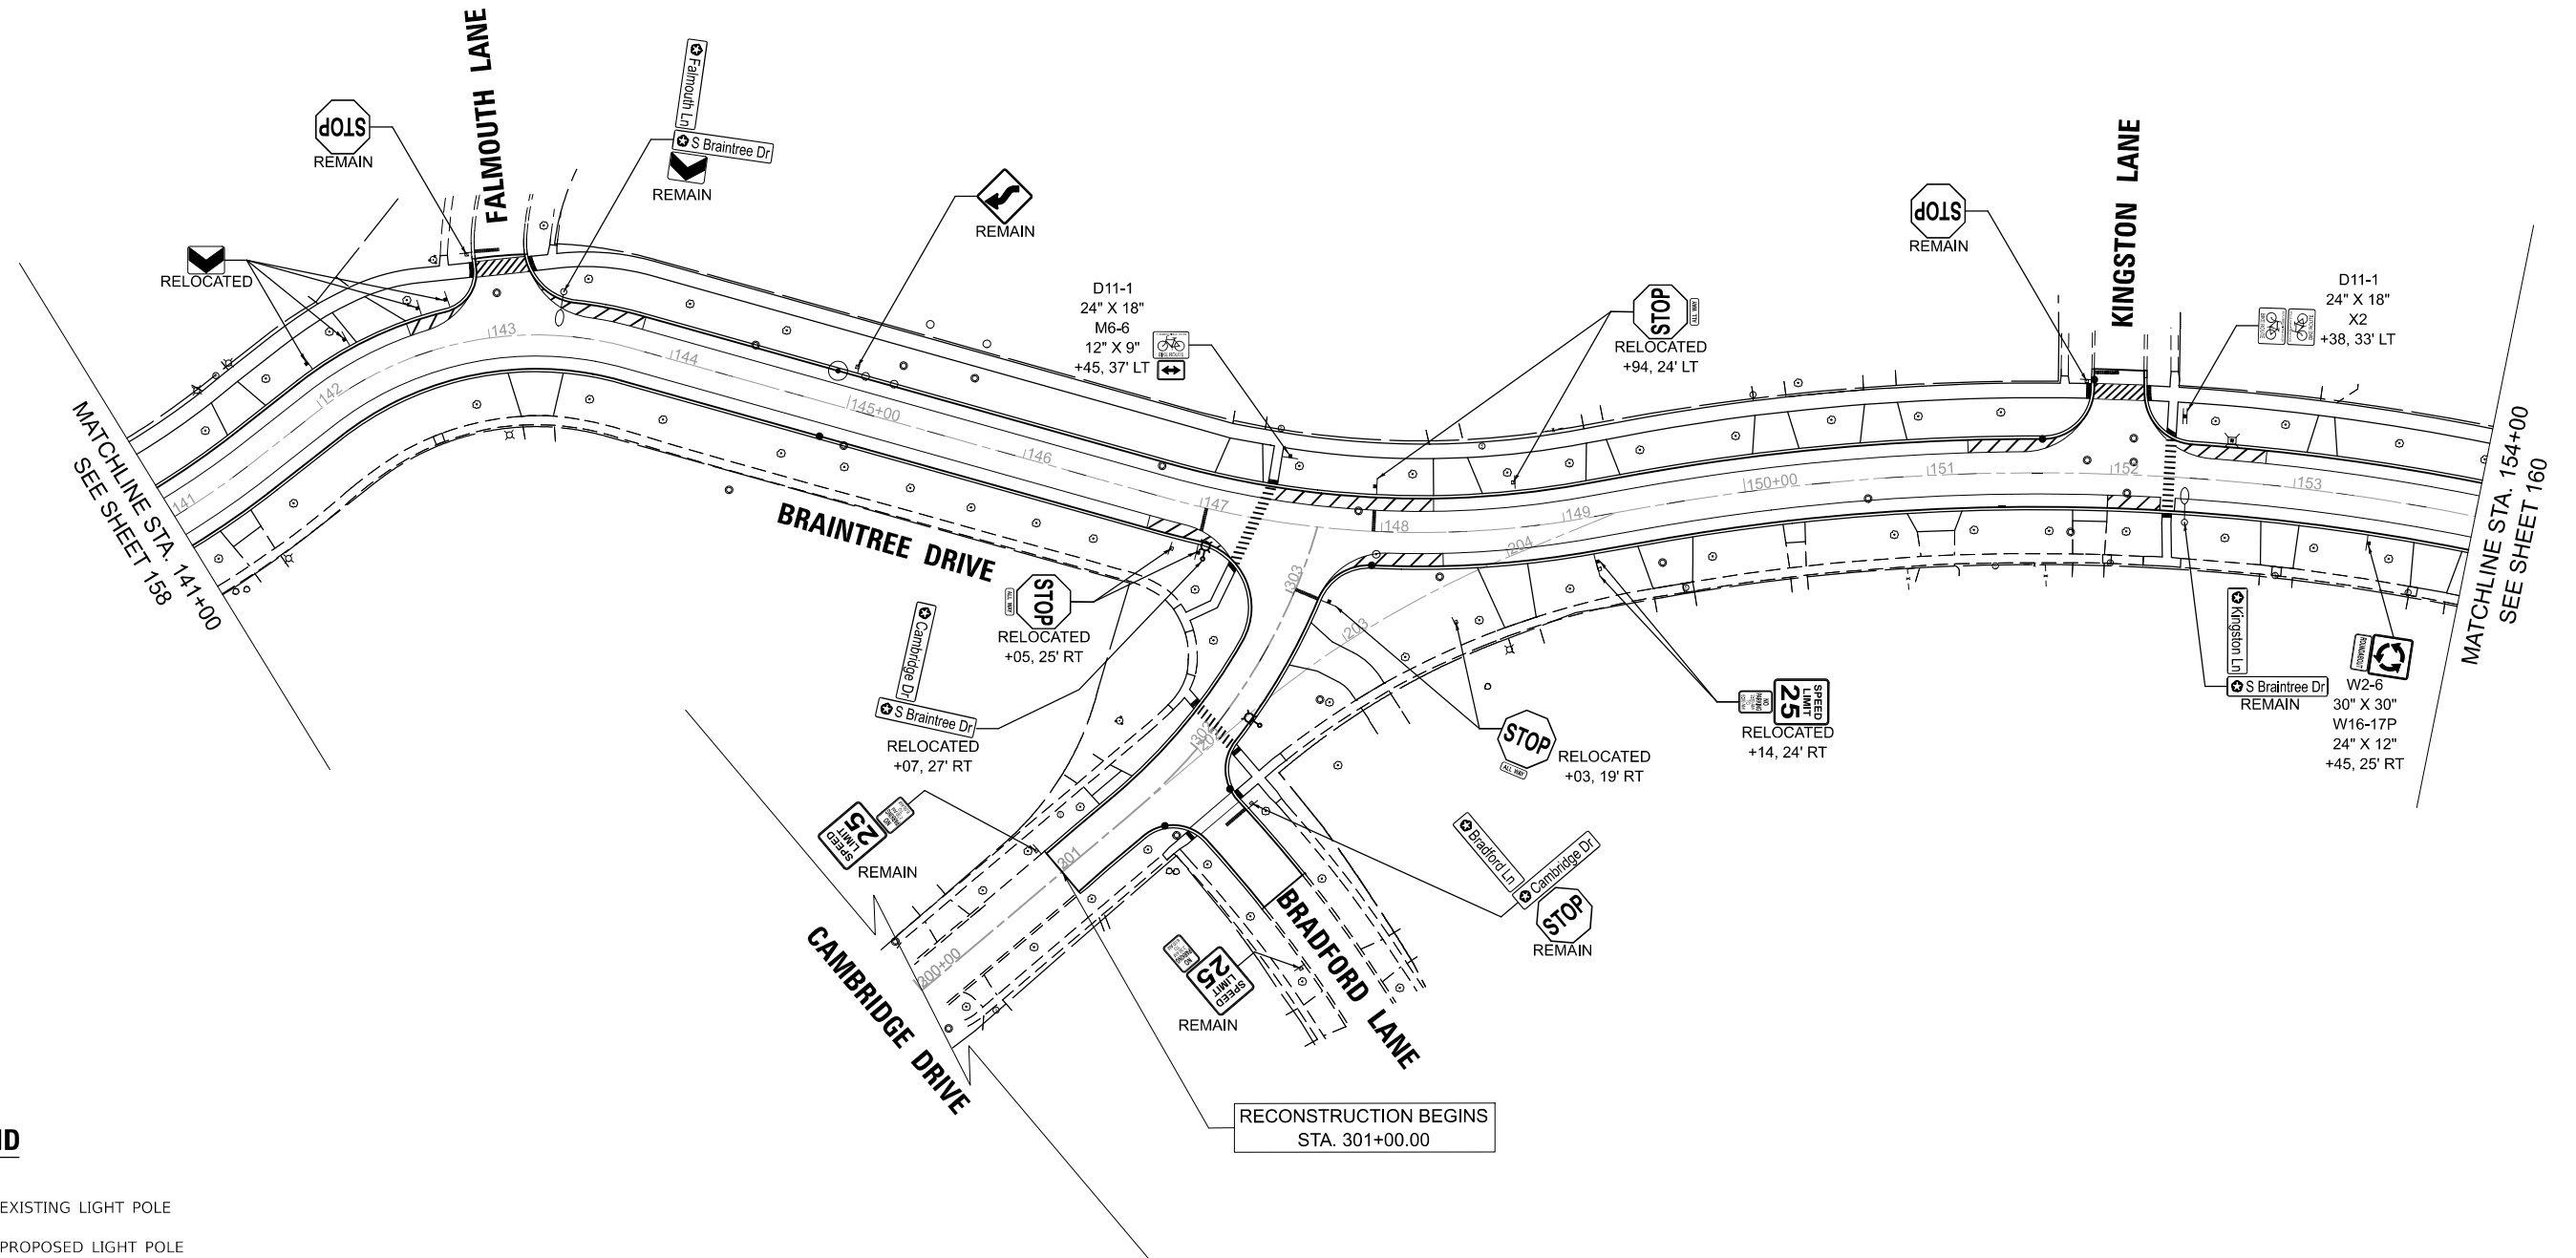

	EXISTING LIGHT POLE
	PROPOSED LIGHT POLE
	EXISTING SIGN TO REMAIN
	PROPOSED SIGN PANEL, TYPE 1 (SPECIAL) OR TYPE 2 (SPECIAL)
REMAIN	SIGN PANEL TO REMAIN IN SAME LOCATION
RELOCATED	SIGN PANEL TO BE RELOCATED

USER NAME = pk	DESIGNED - AMP	REVISED -
	DRAWN - AMP	REVISED -
	CHECKED - PK	REVISED -
PLOT DATE = 12/11/2025	DATE - 12/12/2025	REVISED -

BRAINTREE DRIVE PROPOSED SIGNING PLAN

SCALE: 1"=50'	SHEET 3	OF 4	SHEETS	STA. 141+00.00	TO STA. 154+00.00
---------------	---------	------	--------	----------------	-------------------

MUN RTE.	SECTION	COUNTY	TOTAL SHEETS	SHEET NO.
4029	23-00146-00-PV	COOK	315	159
		CONTRACT NO. 61M26		
		ILLINOIS FED. AID PROJECT		

MODEL: Braintree-1 - Plan 5 [Sheet]
FILE NAME: c:\bms\civiltech-pw\petro.kravets\0140568\3993 Proposed Signing Sheets.dgn

TRAFFIC SIGNAL LEGEND

(NOT TO SCALE)

ITEM	EXISTING	PROPOSED	ITEM	EXISTING	PROPOSED	ITEM	EXISTING	PROPOSED
CONTROLLER CABINET			HANDHOLE -SQUARE -ROUND			SIGNAL HEAD -(P) PROGRAMMABLE SIGNAL HEAD		
COMMUNICATION CABINET			HEAVY DUTY HANDHOLE -SQUARE -ROUND			SIGNAL HEAD WITH BACKPLATE -(P) PROGRAMMABLE SIGNAL HEAD -(RB) RETROREFLECTIVE BACKPLATE		
MASTER CONTROLLER			DOUBLE HANDHOLE			PEDESTRIAN SIGNAL HEAD AT RAILROAD INTERSECTIONS		
MASTER MASTER CONTROLLER			JUNCTION BOX			PEDESTRIAN SIGNAL HEAD WITH COUNTDOWN TIMER		
UNINTERRUPTABLE POWER SUPPLY			RAILROAD CANTILEVER MAST ARM			ILLUMINATED SIGN "NO LEFT TURN"/"NO RIGHT TURN"		
SERVICE INSTALLATION -(P) POLE MOUNTED			RAILROAD FLASHING SIGNAL			NUMBER OF CONDUCTORS, ELECTRIC CABLE NO. 14, UNLESS NOTED OTHERWISE. ALL DETECTOR LOOP CABLE TO BE SHIELDED		
SERVICE INSTALLATION -(G) GROUND MOUNTED -(GM) GROUND MOUNTED METERED			RAILROAD CROSSING GATE			GROUND CABLE IN CONDUIT, NO. 6 SOLID COPPER (GREEN)		
TELEPHONE CONNECTION			RAILROAD CROSSBUCK			ELECTRIC CABLE IN CONDUIT, TRACER NO. 14 1/C		
STEEL MAST ARM ASSEMBLY AND POLE			RAILROAD CONTROLLER CABINET			COAXIAL CABLE		
ALUMINUM MAST ARM ASSEMBLY AND POLE			UNDERGROUND CONDUIT (UC), GALVANIZED STEEL			VENDOR CABLE		
STEEL COMBINATION MAST ARM ASSEMBLY AND POLE WITH LUMINAIRE			TEMPORARY SPAN WIRE, TETHER WIRE, AND CABLE			COPPER INTERCONNECT CABLE, NO. 18, 3 PAIR TWISTED, SHIELDED		
SIGNAL POST -(BM) BARREL MOUNTED - TEMPORARY			SYSTEM ITEM	S	SP	FIBER OPTIC CABLE -NO. 62.5/125, MM12F -NO. 62.5/125, MM12F SM12F -NO. 62.5/125, MM12F SM24F		
WOOD POLE			INTERSECTION ITEM	I	IP			
GUY WIRE			REMOVE ITEM		R			
SIGNAL HEAD			RELOCATE ITEM		RL			
SIGNAL HEAD WITH BACKPLATE			ABANDON ITEM		A			
SIGNAL HEAD OPTICALLY PROGRAMMED			CONTROLLER CABINET AND FOUNDATION TO BE REMOVED		RCF			
FLASHER INSTALLATION -(FS) SOLAR POWERED			MAST ARM POLE AND FOUNDATION TO BE REMOVED		RMF			
			SIGNAL POST AND FOUNDATION TO BE REMOVED		RPF			
PEDESTRIAN SIGNAL HEAD			DETECTOR LOOP, TYPE I					
PEDESTRIAN PUSH BUTTON -(APS) ACCESSIBLE PEDESTRIAN PUSH BUTTON			PREFORMED DETECTOR LOOP					
RADAR DETECTION SENSOR			SAMPLING (SYSTEM) DETECTOR					
VIDEO DETECTION CAMERA			INTERSECTION AND SAMPLING (SYSTEM) DETECTOR					
RADAR/VIDEO DETECTION ZONE			QUEUE AND SAMPLING (SYSTEM) DETECTOR					
PAN, TILT, ZOOM (PTZ) CAMERA			WIRELESS DETECTOR SENSOR					
EMERGENCY VEHICLE LIGHT DETECTOR			WIRELESS ACCESS POINT					
CONFIMATION BEACON								
WIRELESS INTERCONNECT								
WIRELESS INTERCONNECT RADIO REPEATER								

	USER NAME = footemj	DESIGNED - IP	REVISED -	STATE OF ILLINOIS DEPARTMENT OF TRANSPORTATION	DISTRICT ONE STANDARD TRAFFIC SIGNAL DESIGN DETAILS				MUN RTE.	SECTION	COUNTY	TOTAL SHEETS	SHEET NO.
		DRAWN - IP	REVISED -		SCALE: NONE	SHEET 1	OF 7	SHEETS	4029	23-00146-00-PV	COOK	315	161
	PLOT SCALE = 50.0000 ' / in.	CHECKED - LP	REVISED -						TS-05		CONTRACT NO.61M26		
	PLOT DATE = 3/4/2019	DATE - 9/29/2016	REVISED -								ILLINOIS FED. AID PROJECT		

EACH PAIR OF LOOP WIRES SHALL BE PLACED IN A SEPARATE EMPTY COILABLE CONDUIT FROM THE EDGE OF PAVEMENT TO THE HANDHOLE. SPACING BETWEEN THE HOLES DRILLED IN THE PAVEMENT SHALL NOT BE LESS THAN 6" (150 mm). EMPTY COILABLE NONMETALLIC CONDUIT SHALL BE INCLUDED IN THE COST OF THE LOOP WIRE.

THE NUMBER OF LOOP TURNS SHALL BE AS RECOMMENDED BY THE AMPLIFIER MANUFACTURER. ALL ADJACENT SIDES OF THE LOOPS SHALL BE INSTALLED IN SUCH A WAY THAT THE CURRENT FLOW IS IN THE SAME DIRECTION TO REINFORCE ITS MAGNETIC FIELDS FOR SMALL VEHICLE DETECTION.

EACH LOOP LEAD-IN SHALL BE IDENTIFIED AND PERMANENTLY TAGGED IN THE HANDHOLE. EACH LEAD-IN CABLE TAG SHALL INDICATE THE LOCATION OF THE LOOP, LOOP ROTATION (CLOCKWISE/COUNTERCLOCKWISE), LOOP LEAD-IN DIRECTION (IN OR OUT), LOOP CABLE NUMBER AND LOCATION IN CABINET, AND NUMBER OF TURNS IN THE DETECTOR LOOPS IN WATER PROOF INK AS INDICATED ON THE DISTRICT 1 STANDARD TRAFFIC SIGNAL DESIGN DETAIL. THE CONTRACTOR SHALL MARK LOOP LOCATIONS ON RECORD DRAWINGS AND PRESENT TO THE ENGINEER AFTER FINAL INSPECTION. LOOPS SHALL BE MARKED BY LANE AND LOOP NUMBER. SEE DETAIL BELOW.

ALL LOOP CABLE SHALL BE FASTENED WITH PLASTIC TIE WRAP TO THE HANDHOLE HOOKS.

 
IN ASPHALT PAVEMENT, LOOPS SHOULD BE PLACED IN THE BINDER AND DIVEHOLES MARKED AT THE CURB WITH A SAW-CUT. THE SAW-CUT SHALL BE CUT IN ACCORDANCE WITH LOCAL AND E.P.A. DUST CONTROL REQUIREMENTS. DETECTOR LOOP(S) SHALL NOT BE INSTALLED IN WET CONDITIONS AND THE SAW-CUTS MUST BE FREE OF DEBRIS AND RESIDUE SUCH AS DUST AND WATER WHICH IS TO BE ACHIEVED BY THE USE OF COMPRESSED AIR, WIRE BRUSHING AND HEAT DRYING ACCORDING TO SEALANT MANUFACTURER REQUIREMENTS. THE DETECTOR WIRE SHALL BE HELD IN PLACE BY THE USE OF FORM WEDGES. WEDGES SHALL BE SPACED NO MORE THAN 18" (450 mm) APART.

LOOP SPLICES SHALL BE SOLDERED USING A SOLDERING IRON. BLOW TORCHES OR OTHER DEVICES WHICH OXIDIZE COPPER CABLE SHALL NOT BE ALLOWED FOR SOLDERING OPERATIONS. SEE DETAIL BELOW RIGHT.


PREFORMED DETECTOR LOOPS SHALL BE USED, AS SHOWN ON THE PLANS, WHERE NEW CONCRETE PAVEMENT IS PROPOSED. THE INSTALLATION OF PREFORMED LOOPS SHALL BE IN ACCORDANCE WITH THE DISTRICT 1 SPECIFICATIONS OR AS DIRECTED BY THE ENGINEER.



- LOOPS SHALL BE SPLICED IN SERIES.
- SAW-CUTS SHALL BE A MINIMUM WIDTH OF 5/16" (8 mm).
- SAW-CUT DEPTHS SHALL BE 3" (75 mm). IF IN CONCRETE,
- THE SAW-CUT DEPTH SHALL BE TO THE TOP OF THE REINFORCEMENT.
- LOOP CORNERS SHALL BE DRILLED WITH A 2" (50 mm) DIAMETER CORE.




TYPE I LOOP

 

PRE-FORMED LOOP

LOOP DETECTOR SPLICE

- | | |
|---|--|
| <p>① WESTERN UNION SPlice SOLDERED WITH ROSIN CORE FLUX. ALL EXPOSED SURFACES OF THE SOLDER SHALL BE SMOOTH. THE WESTERN UNION SPLICES SHALL BE STAGGERED.</p> <p>② WCSMW 30/100 HEAT SHRINK TUBE, MINIMUM LENGTH 3" (75 mm), UNDERWATER GRADE.</p> <p>③ WCS 200/750 HEAT SHRINK TUBE, MINIMUM LENGTH 6" (150 mm), UNDERWATER GRADE.</p> <p>④ NO. 14 2/C TWISTED, SHIELDED CABLE.</p> | <p>⑤ LOOP CONDUCTOR WITH FLEXIBLE PLASTIC TUBE. PRE-FORMED LOOP</p> <p>⑥ XL POLYOLEFIN 2 CONDUCTOR</p> <p>⑦ BREAKOUT SEALS. TYCO CBR-2 OR APPROVED EQUAL</p> |
|---|--|

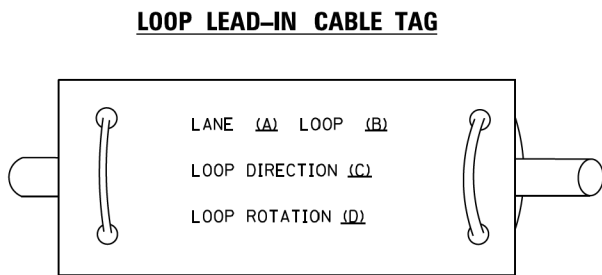


- A. LANE 1 IS THE LANE CLOSEST TO THE CENTERLINE OF THE ROADWAY.
- B. LOOP #1 IS THE LOOP IN THE LANE CLOSEST TO THE INTERSECTION.
- C. LABEL LOOP CABLE "IN" OR LOOP CABLE "OUT".
- D. LABEL LOOP CABLE CLOCKWISE OR LOOP CABLE COUNTERCLOCKWISE.

	USER NAME = footemj	DESIGNED -	REVISED -	STATE OF ILLINOIS DEPARTMENT OF TRANSPORTATION	DISTRICT ONE				MUN RTE.	SECTION	COUNTY	TOTAL SHEETS	SHEET NO.
		DRAWN -	REVISED -		STANDARD TRAFFIC SIGNAL DESIGN DETAILS				4029	23-00146-00-PV	COOK	315	162
	PLOT SCALE = 50,0000 ' / in.	CHECKED -	REVISED -						TS-05		CONTRACT NO.61M26		
	PLOT DATE = 3/4/2019	DATE -	REVISED -		SCALE: NONE SHEET 2 OF 7 SHEETS STA. TO STA.				ILLINOIS FED. AID PROJECT				

MODEL: Default
FILE NAME: Proj\ILL0848EB\INDTEC\Illroads.gov\PIV\DOT\Documents\DOT_Offices\District_1\Projects\DH45422\24\CAD\Data\CADsheetst05.dgn
h05.dgn 3/4/2019 11:22:44 AM User=footem

TRAFFIC SIGNAL MAST ARM AND SIGNAL POST


MAST ARM MOUNTED SIGNALS IN EXISTING, PROPOSED OR FUTURE SIDEWALK/BICYCLE PATH AREA. INTERSECTION SHOWN WITH PEDESTRIAN SIGNALS AND PEDESTRIAN PUSHBUTTON DETECTORS.

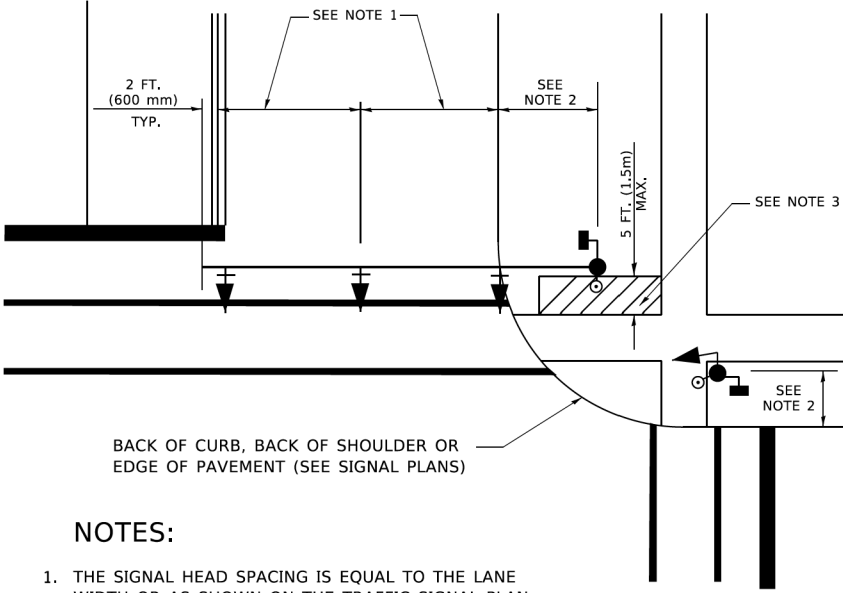

NOTES:

1. THE SIGNAL HEAD SPACING IS EQUAL TO THE LANE WIDTH OR AS SHOWN ON THE TRAFFIC SIGNAL PLAN.
2. REFER TO THE TRAFFIC SIGNAL EQUIPMENT OFFSET TABLE.
3. PROVIDE A LEVEL ALL-WEATHER SURFACE (CONCRETE SIDEWALK, ASPHALT BICYCLE PATH SURFACE OR MATCHING MATERIAL TO THE ADJACENT SURFACE) UP TO THE MAST ARM SHAFT OR THE SIGNAL POST.
4. THE FACE OF THE PEDESTRIAN PUSHBUTTON SHALL BE PARALLEL TO THE CROSSWALK TO BE USED.
5. THE LOCATIONS AND INSTALLATION OF PEDESTRIAN SIGNAL HEADS AND PEDESTRIAN PUSHBUTTONS SHALL MEET THE REQUIREMENTS OF THE MUTCD AND INFORMATION FOUND IN THE "AMERICANS WITH DISABILITIES ACT ACCESSIBILITY GUIDELINES FOR BUILDINGS AND FACILITIES."


PEDESTRIAN SIGNAL POST
AND
PEDESTRIAN PUSH BUTTON POST

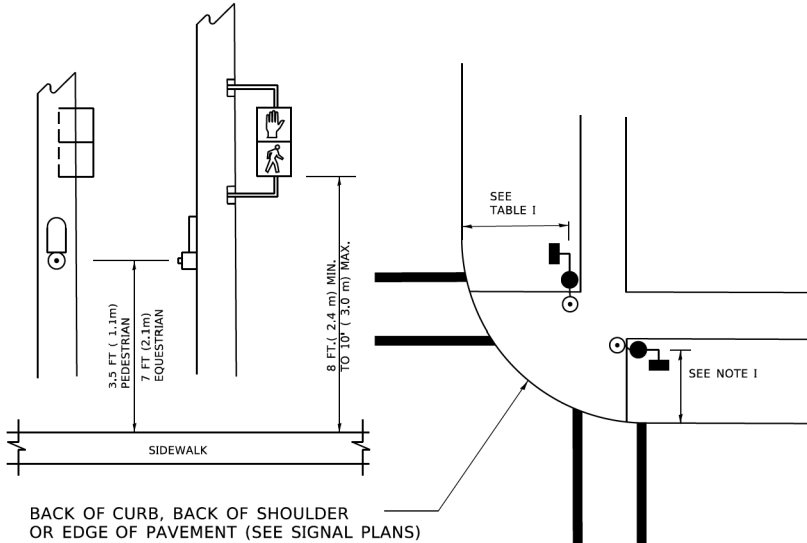

NOTES:

1. REFER TO THE TRAFFIC SIGNAL EQUIPMENT OFFSET TABLE.
2. PROVIDE A LEVEL ALL-WEATHER SURFACE (CONCRETE SIDEWALK, ASPHALT BICYCLE PATH SURFACE OR MATCHING MATERIAL TO THE ADJACENT SURFACE) UP TO THE PEDESTRIAN SIGNAL POST OR THE PEDESTRIAN PUSH BUTTON POST.
3. THE FACE OF THE PEDESTRIAN PUSHBUTTON SHALL BE PARALLEL TO THE CROSSWALK TO BE USED.
4. THE LOCATIONS AND INSTALLATION OF PEDESTRIAN SIGNAL HEADS AND PEDESTRIAN PUSHBUTTONS SHALL MEET THE REQUIREMENTS OF THE MUTCD AND INFORMATION FOUND IN THE "AMERICANS WITH DISABILITIES ACT ACCESSIBILITY GUIDELINES FOR BUILDINGS AND FACILITIES."

RECOMMENDED PUSHBUTTON LOCATIONS

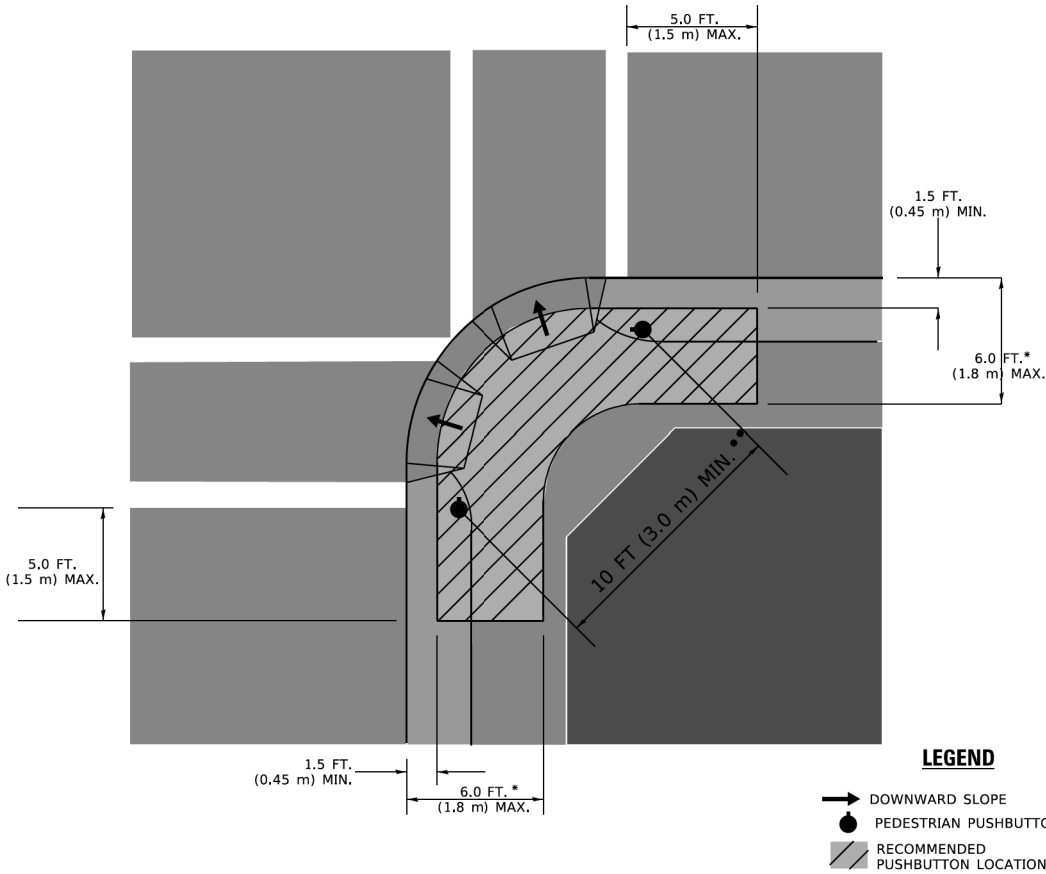

- * WHERE THERE ARE CONSTRAINTS THAT MAKE IT IMPRACTICAL TO PLACE THE PEDESTRIAN PUSHBUTTON BETWEEN 1.5 FT (0.45 m) AND 6 FT (1.8 m) FROM THE EDGE OF THE CURB, SHOULDER, OR PAVEMENT, IT SHOULD NOT BE FURTHER THAN 10 FT (3 m) FROM THE EDGE OF CURB, SHOULDER, OR PAVEMENT.
- ** WHERE THERE ARE CONSTRAINTS ON A PARTICULAR CORNER THAT MAKE IT IMPRACTICAL TO PROVIDE THE 10 FT (3 m) SEPERATION BETWEEN THE TWO PEDESTRIAN PUSHBUTTONS, THE PUSHBUTTONS MAY BE PLACED CLOSER TOGETHER OR ON THE SAME POLE.

NOTES:

1. PEDESTRIAN SIGNAL HEADS SHALL BE MOUNTED WITH THE BOTTOM OF THE SIGNAL HOUSING INCLUDING BRACKETS NOT LESS THAN 8 FT (2.4 m) OR MORE THAN 10 FT (3 m) ABOVE SIDEWALK LEVEL, AND SHALL BE POSITIONED AND ADJUSTED TO PROVIDE MAXIMUM VISIBILITY AT THE BEGINNING OF THE CONTROLLED CROSSWALK.
2. THE BOTTOM OF THE SIGNAL HOUSING (INCLUDING BRACKETS) OF A VEHICULAR SIGNAL FACE THAT IS NOT LOCATED OVER A HIGHWAY SHALL BE AT LEAST 8 FT (2.4 m) BUT NOT MORE THAN 19 FT (5.8 m) ABOVE THE SIDEWALK OR, IF THERE IS NO SIDEWALK, ABOVE THE PAVEMENT GRADE AT THE CENTER OF THE ROADWAY.
3. THE BOTTOM OF THE SIGNAL HOUSING AND ANY RELATED ATTACHMENTS TO A SIGNAL FACE LOCATED OVER ANY PORTION OF A HIGHWAY SHALL BE ACCORDING TO CURRENT STATE STANDARDS 877001, 877002, 877006, 877011 AND 877012 WITH A MINIMUM OF 16 FT (5.0 m) AND A MAXIMUM OF 18 FT. (5.5 m) FROM THE HIGHEST POINT OF PAVEMENT.
4. THE BOTTOM OF THE TEMPORARY SPAN WIRE MOUNTED SIGNAL HOUSING AND ANY RELATED ATTACHMENTS TO A SIGNAL FACE LOCATED OVER ANY PORTION OF A HIGHWAY SHALL BE ACCORDING TO CURRENT STATE STANDARD 880001 WITH A MINIMUM OF 17 FT (5.18 m) FROM THE HIGHEST POINT OF PAVEMENT.
5. THE TOP OF THE SIGNAL HOUSING OF A SIGNAL FACE LOCATED OVER ANY PORTION OF A HIGHWAY SHALL NOT BE MORE THAN 25.6 FT (7.8 m) ABOVE THE PAVEMENT.

TRAFFIC SIGNAL EQUIPMENT OFFSET


TRAFFIC SIGNAL EQUIPMENT	COMBINATION CONCRETE CURB AND GUTTER (MINIMUM DISTANCE FROM BACK OF CURB TO CENTERLINE OF FOUNDATION)	SHOULDER/NON-CURBED AREA (MINIMUM DISTANCE FROM EDGE OF PAVEMENT TO CENTERLINE OF FOUNDATION)
TRAFFIC SIGNAL MAST ARM POLE	6 FT (1.8m)	SHOULDER WIDTH + 2 FT (0.6m), MINIMUM 10 FT (3.0m)
TRAFFIC SIGNAL POST	4 FT (1.2m)	SHOULDER WIDTH + 2 FT (0.6m), MINIMUM 10 FT (3.0m)
PEDESTRIAN SIGNAL POST	4 FT (1.2m)	SHOULDER WIDTH + 2 FT (0.6m), MINIMUM 10 FT (3.0m)
PEDESTRIAN PUSHBUTTON POST	4 FT (1.2m)	SHOULDER WIDTH + 2 FT (0.6m), MINIMUM 10 FT (3.0m)
TEMPORARY WOOD POLE	6 FT (1.8m)	SHOULDER WIDTH + 2 FT (0.6m), MINIMUM 10 FT (3.0m)
CONTROLLER CABINET	6 FT (1.8m) MINIMUM DISTANCE SEE NOTE 2	SHOULDER WIDTH + 6 FT (1.8m), MINIMUM 16 FT (4.9m) SEE NOTE 3.
SERVICE INSTALLATION, GROUND MOUNT	6 FT (1.8m) MINIMUM DISTANCE SEE NOTE 2	SHOULDER WIDTH + 6 FT (1.8m), MINIMUM 16 FT (4.9m) SEE NOTE 3.

NOTES:


1. CONTACT THE "AREA TRAFFIC SIGNAL MAINTENANCE AND OPERATIONS ENGINEER" FOR ASSISTANCE IN LOCATING THE TRAFFIC SIGNAL EQUIPMENT WHEN THERE ARE CONFLICTS WITH DITCHES OR THE MINIMUM OFFSET DISTANCES CANNOT BE MET.
2. MINIMUM DISTANCE FROM THE BACK OF CURB TO THE ROADWAY SIDE OF THE FOUNDATION.
3. MINIMUM DISTANCE FROM THE EDGE OF PAVEMENT TOTHE ROADWAY SIDE OF THE FOUNDATION.
4. ANY CHANGES TO THE OFFSETS OF THE FOUNDATIONS, FROM THE MINIMUM DISTANCES LISTED IN THE "TRAFFIC SIGNAL EQUIPMENT OFFSET" CHART AND THE TRAFFIC SIGNAL INSTALLATION PLAN, COULD EFFECT THE PLACEMENT OF THE SIGNAL HEADS, PEDESTRIAN SIGNAL HEADS AND THE PEDESTRIAN PUSHBUTTONS. THE SIGNAL HEAD PLACEMENT ON THE MAST ARMS SHALL REMAIN AS PER THE TRAFFIC SIGNAL INSTALLATION PLAN AND THE "TRAFFIC SIGNAL MAST ARM AND SIGNAL POST" DETAIL ABOVE. THE PROPOSED MAST ARM LENGTHS MAY NEED TO BE REVISED TO MEET THE ABOVE REQUIREMENTS. THE PEDESTRIAN SIGNAL HEADS AND PEDESTRIAN PUSHBUTTONS MUST MEET THE REQUIREMENTS UNDER THE DETAILS ON THIS SHEET.

USER NAME = footemj	DESIGNED -	REVISED -	STATE OF ILLINOIS DEPARTMENT OF TRANSPORTATION	DISTRICT ONE STANDARD TRAFFIC SIGNAL DESIGN DETAILS				MUN RTE.	SECTION	COUNTY	TOTAL SHEETS	SHEET NO.
	DRAWN -	REVISED -						4029	23-00146-00-PV	COOK	315	163
PLOT SCALE = 50.0000 ' / in.	CHECKED -	REVISED -		TS-05		CONTRACT NO.61M26						
PLOT DATE = 3/4/2019	DATE -	REVISED -		SCALE: NONE	SHEET 3	OF 7	SHEETS	STA.	TO STA.			
								ILLINOIS FED. AID PROJECT				


MODEL: Default
FILE NAME: p:\ul0848\BID\ITEC\Illinois.gov\PIV\DOT\Documents\DOT Office\District 1\Projects\DH4542234\CAD\Data\CAD\sheetst05.dgn

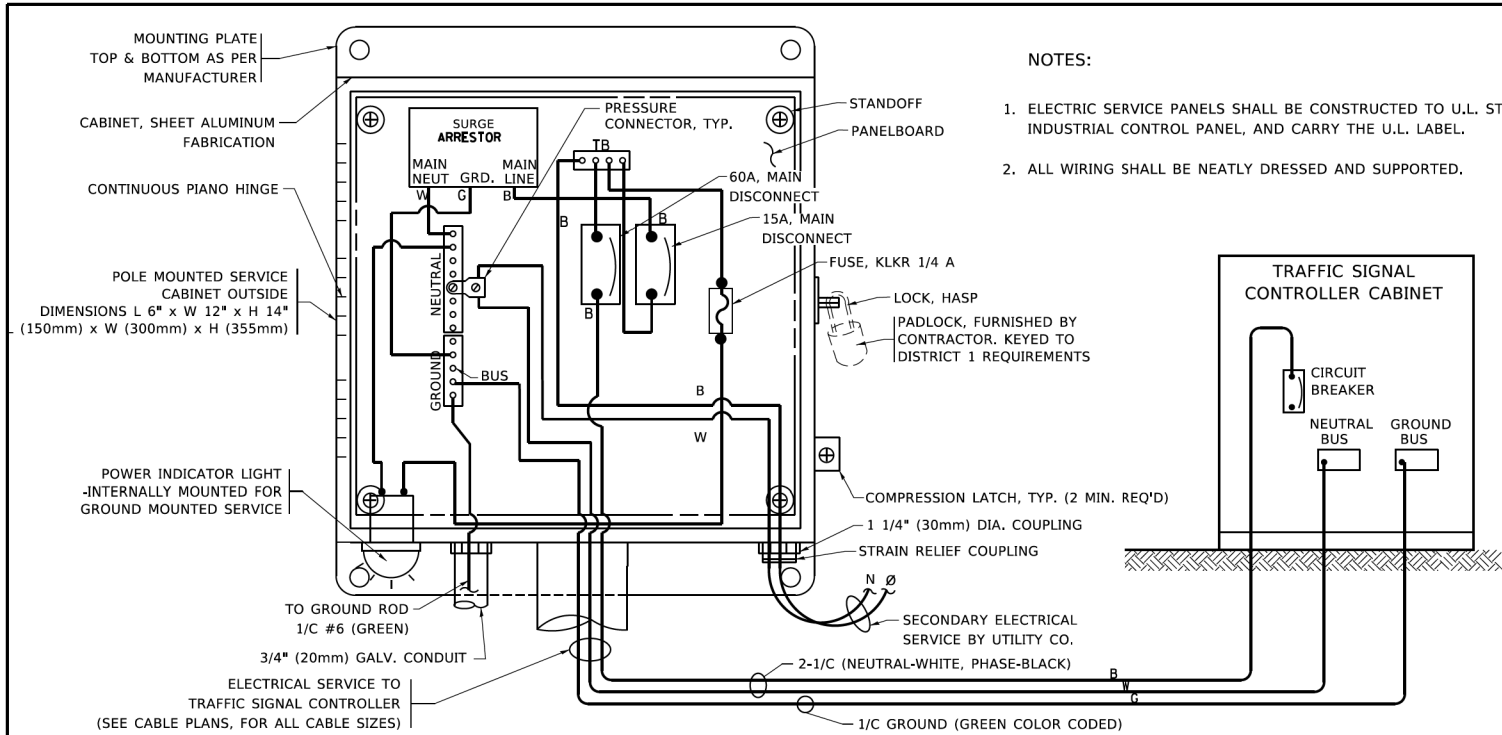


ELECTRICAL SERVICE – PANEL DIAGRAM (TYPICAL FOR POLE AND GROUND MOUNTED SERVICE)
SERVICE INSTALLATION POLE MOUNT (SHOWN)
(NOT TO SCALE)

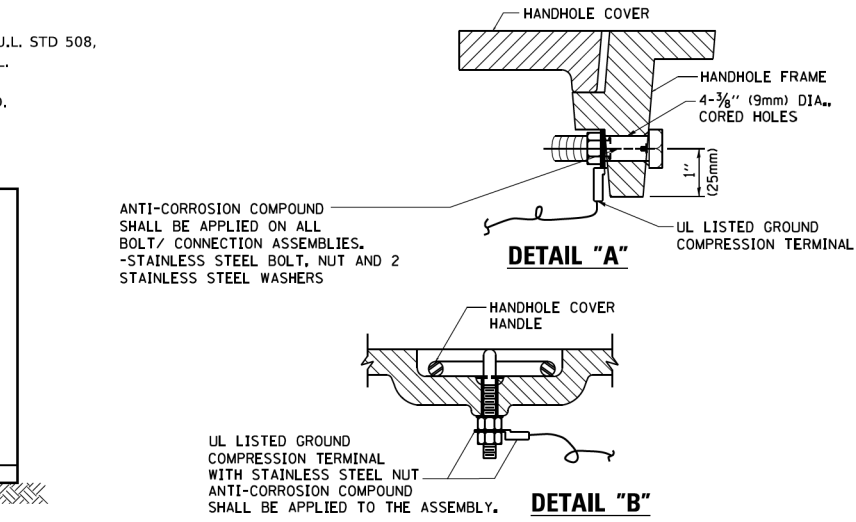


HANDHOLE COVER & FRAME – GROUNDING DETAIL
(NOT TO SCALE)

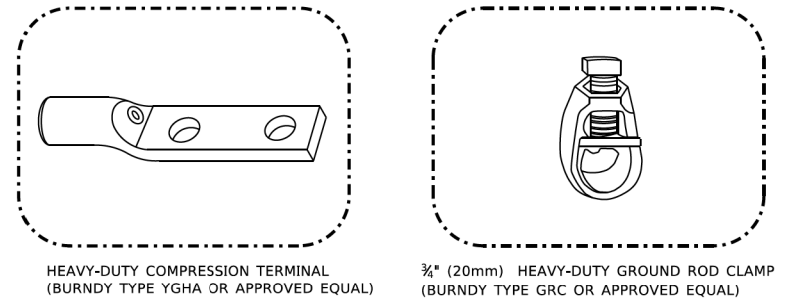

- NOTES:
- ALL CLAMPS SHALL BE BRONZE OR COPPER, UL APPROVED.
 - GROUND CABLE SHALL BE LOOPED OVER HOOKS IN THE HANDHOLES 6.5' (2.0m) SLACK SHALL BE PROVIDED IN SINGLE HANDHOLES 13' (4.0m) OF SLACK SHALL BE PROVIDED IN DOUBLE HANDHOLES. 5' (1.4m) OF SLACK SHALL BE PROVIDED BETWEEN FRAME AND COVER.

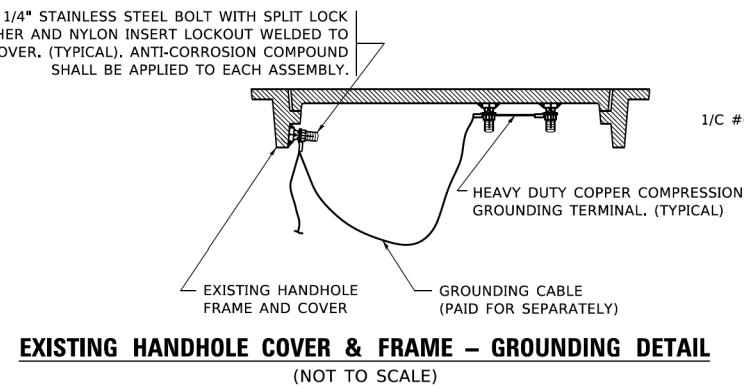


EXISTING HANDHOLE COVER & FRAME – GROUNDING DETAIL
(NOT TO SCALE)

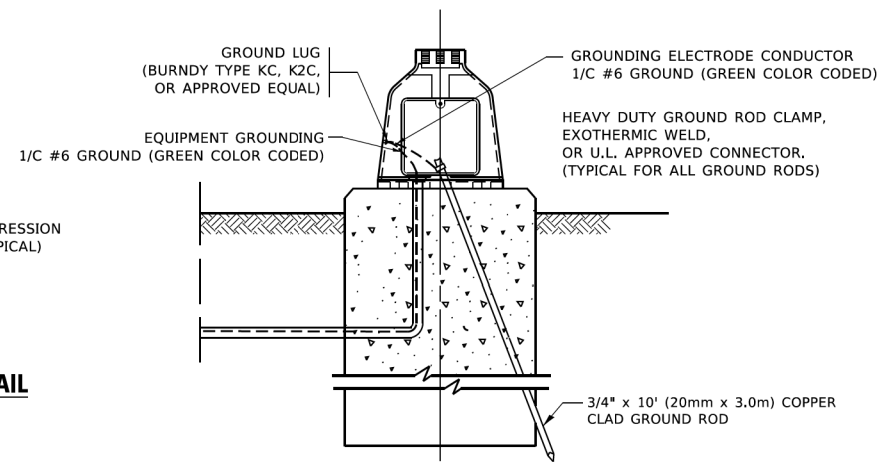

MAST ARM POLE /POST-GROUNDING DETAIL
(NOT TO SCALE)

SERVICE INSTALLATION GROUND MOUNT
(NOT TO SCALE)

CABINET – BASE BOLT PATTERN
(NOT TO SCALE)

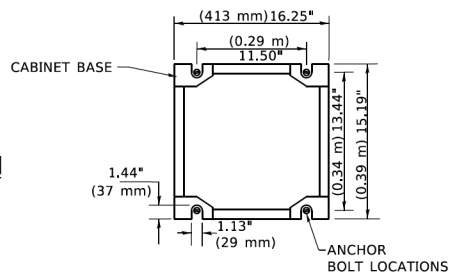


STATE OF ILLINOIS
DEPARTMENT OF TRANSPORTATION

DISTRICT ONE
STANDARD TRAFFIC SIGNAL DESIGN DETAILS

SCALE: NONE SHEET 4 OF 7 SHEETS STA. TO STA.

MUN RTE.	SECTION	COUNTY	TOTAL SHEETS	SHEET NO.
4029	23-00146-00-PV	COOK	315	164
TS-05		CONTRACT NO.61M26		
		ILLINOIS FED. AID PROJECT		

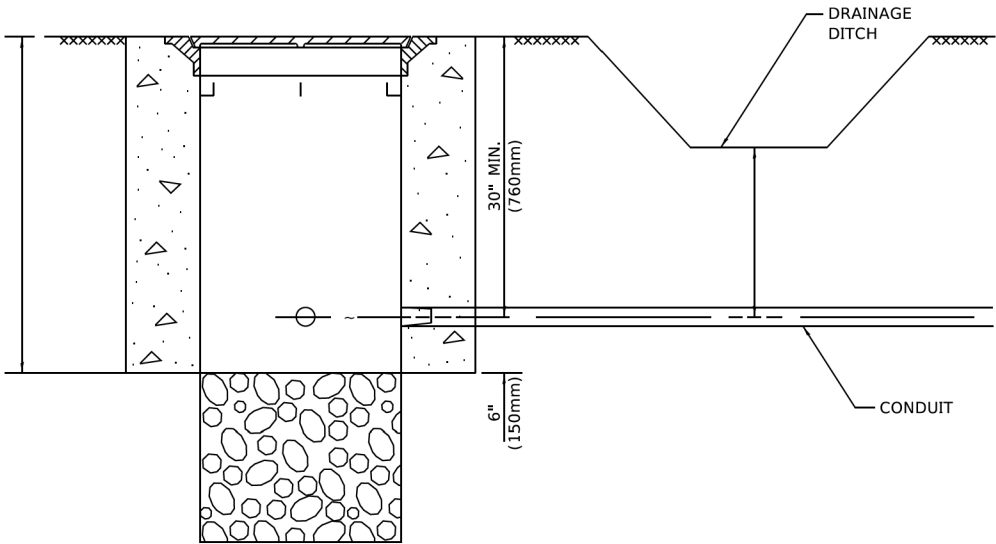


NOTES:

- CONDUIT DEPTH SHALL BE A MINIMUM OF 30" (760mm) BELOW THE BOTTOM OF THE DRAINAGE DITCH OR ANY SLOPING GROUND
- THE MINIMUM CONDUIT DEPTH APPLIES TO ALL CONDUIT PLACED UNDER ROADWAY PAVEMENT, MULTI-USE PATHS, SIDEWALKS AND SOIL SURFACES.
- THE MINIMUM CONDUIT DEPTH APPLIES TO ALL HANDHOLES, HEAVY DUTY HANDHOLES AND DOUBLE HANDHOLES.

HANDHOLE WITH MINIMUM CONDUIT DEPTH


(NOT TO SCALE)

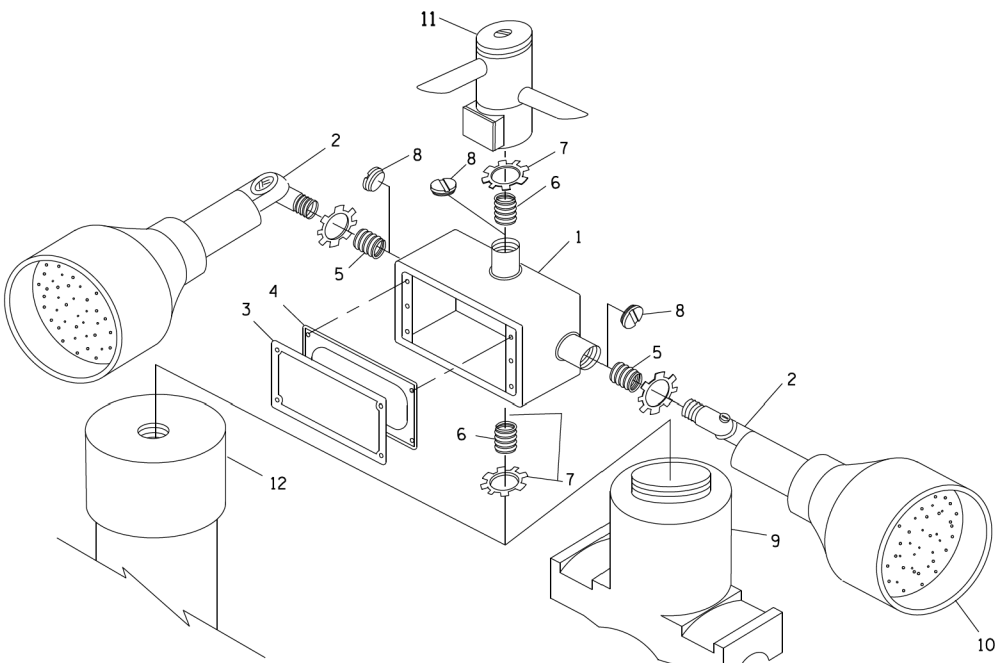

POST CAP MOUNT


MAST ARM MOUNT

EMERGENCY VEHICLE DETECTOR WITH CONFIRMATION BEACON MOUNTING DETAIL

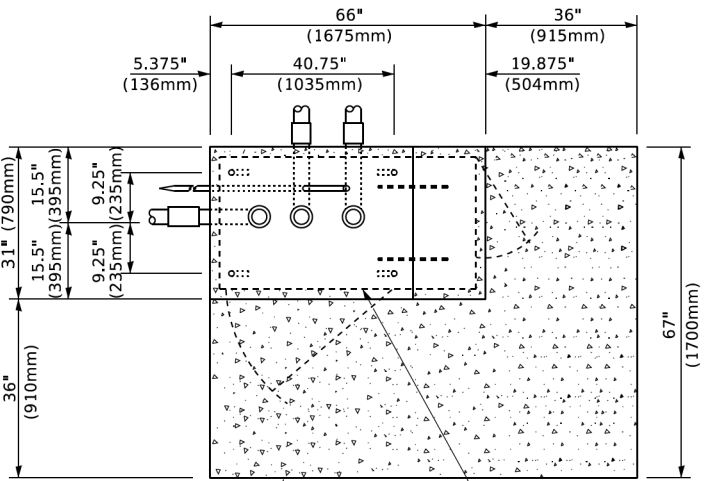

TOP VIEW

(NOT TO SCALE)

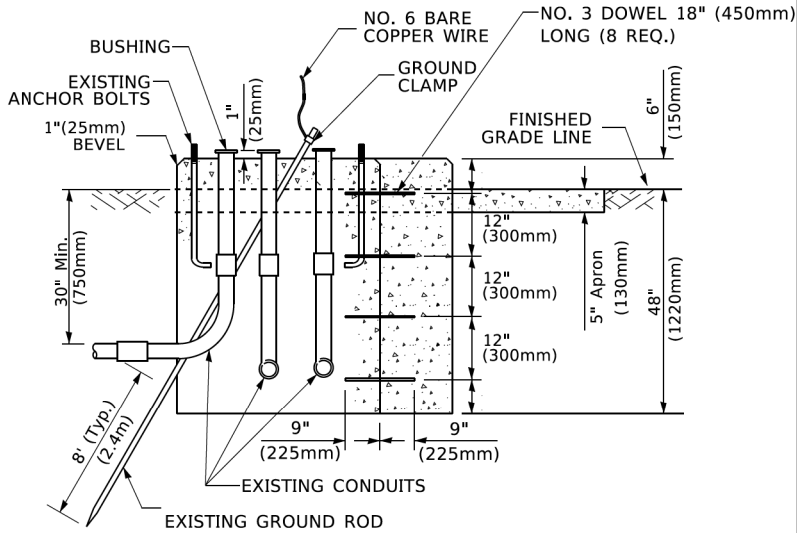


MODIFY EXISTING TYPE "D" FOUNDATION TO TYPE "C" FOUNDATION

(NOT TO SCALE)

ITEM NO.	IDENTIFICATION
1	OUTLET BOX- GALV. 21 CU.IN. (0.000344 CU-M)
2	LAMP HOLDER AND COVER
3	OUTLET BOX COVER
4	RUBBER COVER GASKET
5	REDUCING BUSHING
6	3/4"(19 mm) CLOSE NIPPLE
7	3/4"(19 mm) LOCKNUT
8	3/4"(19 mm) HOLE PLUG
9	SADDLE BRACKET - GALV.
10	6 WATT PAR 38 LED FLOOD LAMP
11	DETECTOR UNIT
12	POST CAP [18 FT. (5.4 m) POST MIN.]

NOTES:

- ALL ELECTRICAL ITEMS, EXCEPT ITEMS #2 AND #11 SHALL BE ALUMINUM OR GALVANIZED
- ITEM #1- OZ/GEDNEY FSX-1-50 OR EQUIVALENT
ITEM #2- MULBERRY CON-O-SHADE LAMP SHIELD OR EQUIVALENT
ITEM #9- "BAND-IT" SADDLE BRACKET OR EQUIVALENT
- WHEN POST MOUNTING IS SPECIFIED, ITEM #9 SHALL NOT BE REQUIRED. THE DETECTION UNIT SHALL BE MOUNTED DIRECTLY ON TOP OF THE CAP BY DRILLING AND TAPPING A 3/4 "(19 mm) HOLE WITH PIPE THREADS. THE POST CAP SHALL EITHER BE SCREWED TO THE TOP OF THE POST OR A MINIMUM OF 3 TIGHTENING SCREWS SHALL BE REQUIRED ON EACH CAP.

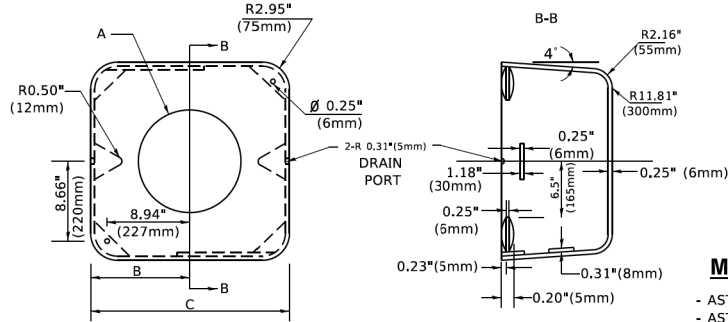

MATERIAL

- ASTM A36 STEEL
- ASTM A-123 HOT DIPPED GALVANIZED

A	B	C	HEIGHT	WEIGHT
VARIES	9.5"(241mm)	19"(483mm)	7" (178mm) - 12" (300mm)	53 lbs (24kg)
VARIES	10.75"(273mm)	21.5"(546mm)	7" (178mm) - 12" (300mm)	68 lbs (31 kg)
VARIES	13.0"(330mm)	26"(660mm)	7" (178mm) - 12" (300mm)	81 lbs (37 kg)
VARIES	18.5"(470mm)	37"(940mm)	7" (178mm) - 12" (300mm)	126 lbs (57 kg)


SHROUD

NOTES:


- DIMENSION "A" IS EQUAL TO THE DIAMETER OF THE MAST ARM POLE AT THE TOP OF THE SHROUD. THE SHROUD SHALL BE TIGHT TO THE MAST ARM POLE.
- THE SUPPLIER SHALL VERIFIED THE ABOVE DIMENSIONS BASED ON MAST ARM REQUIREMENTS.
- THE HEIGHT OF THE SHROUD SHALL COVER THE ANCHOR BOLTS, NUTS AND MAST ARM POLE BASE.

NOTE:

SUPPORT EXISTING CABINET AND CONTROL EQUIPMENT ABOVE FOUNDATION TO KEEP TRAFFIC SIGNAL FUNCTIONING WHILE FOUNDATION MODIFICATION WORK IS PROCEEDING.

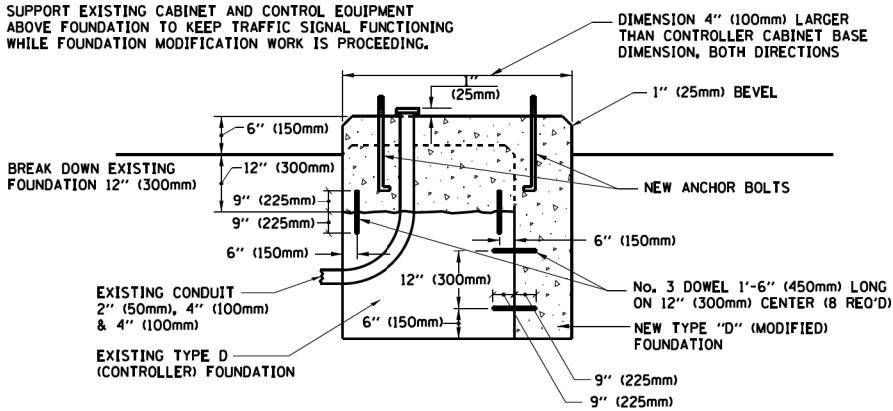

MODIFY EXISTING TYPE "D" FOUNDATION

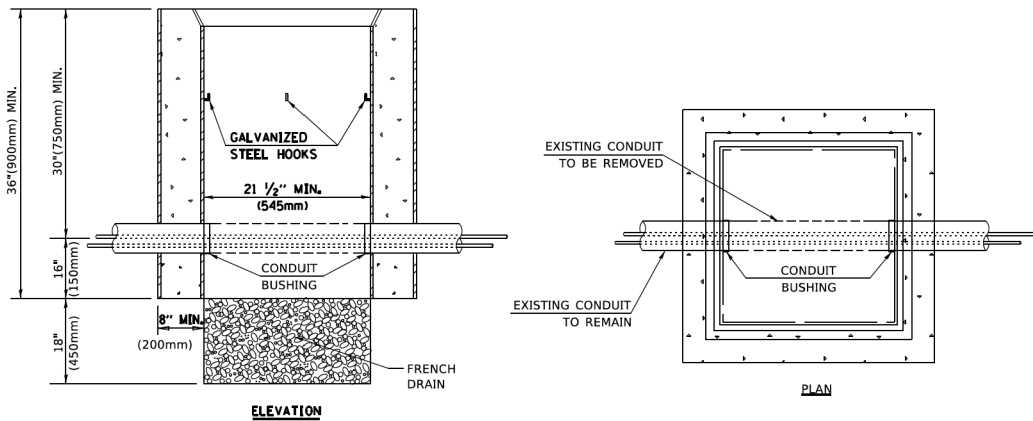

NOTES:

- HANDHOLE CONSTRUCTED PER STATE STANDARD 814001.
- REMOVAL OF THE EXISTING CONDUIT FROM THE HANDHOLE AND THE INSTALLATION OF THE CONDUIT BUSHINGS SHALL BE INCLUDED WITH THE COST OF THE HANDHOLE.

HANDHOLE TO INTERCEPT EXISTING CONDUIT

MODEL: Default
FILE NAME: p:\m\0848\BID\NTEC\Illinois.gov-PVIDOT\Documents\DOT Offices\District 1\Projects\DH4542234\CADData\CADsheetst05.dgn
h05.dwg 3/4/2019 11:23:51 AM User=footem

USER NAME = footem]	DESIGNED -	REVISED -
DRAWN -	REVISED -	REVISED -
PLOT SCALE = 50.0000 ' / in.	CHECKED -	REVISED -
PLOT DATE = 3/4/2019	DATE -	REVISED -

STATE OF ILLINOIS DEPARTMENT OF TRANSPORTATION

DISTRICT ONE STANDARD TRAFFIC SIGNAL DESIGN DETAILS

SCALE: NONE SHEET 6 OF 7 SHEETS STA. TO STA.

MUN RTE.	SECTION	COUNTY	TOTAL SHEETS	SHEET NO.
4029	23-00146-00-PV	COOK	315	166
TS-05		CONTRACT NO.61M26		
ILLINOIS		FED. AID PROJECT		




CONCRETE FOUNDATION,
TYPE A 12-INCH DIAMETER



1. THE SIGN PANELS SHALL BE TYPE AP SHEETING.
2. THE ARROW ON SIGNS FOR PUSH-BUTTONS SERVING TWO DIRECTIONS ON THE SAME PHASE SHALL BE BI-DIRECTIONAL.
3. THE SIGN FOR DUAL-CALL PUSH-BUTTONS SHALL HAVE NO ARROW.

MODEL: Plan [Sheet]
FILE NAME: c:\bms\civiltech-pw\patro.kravets\0140570\3993_Wise Road - Signal Plan.dgn

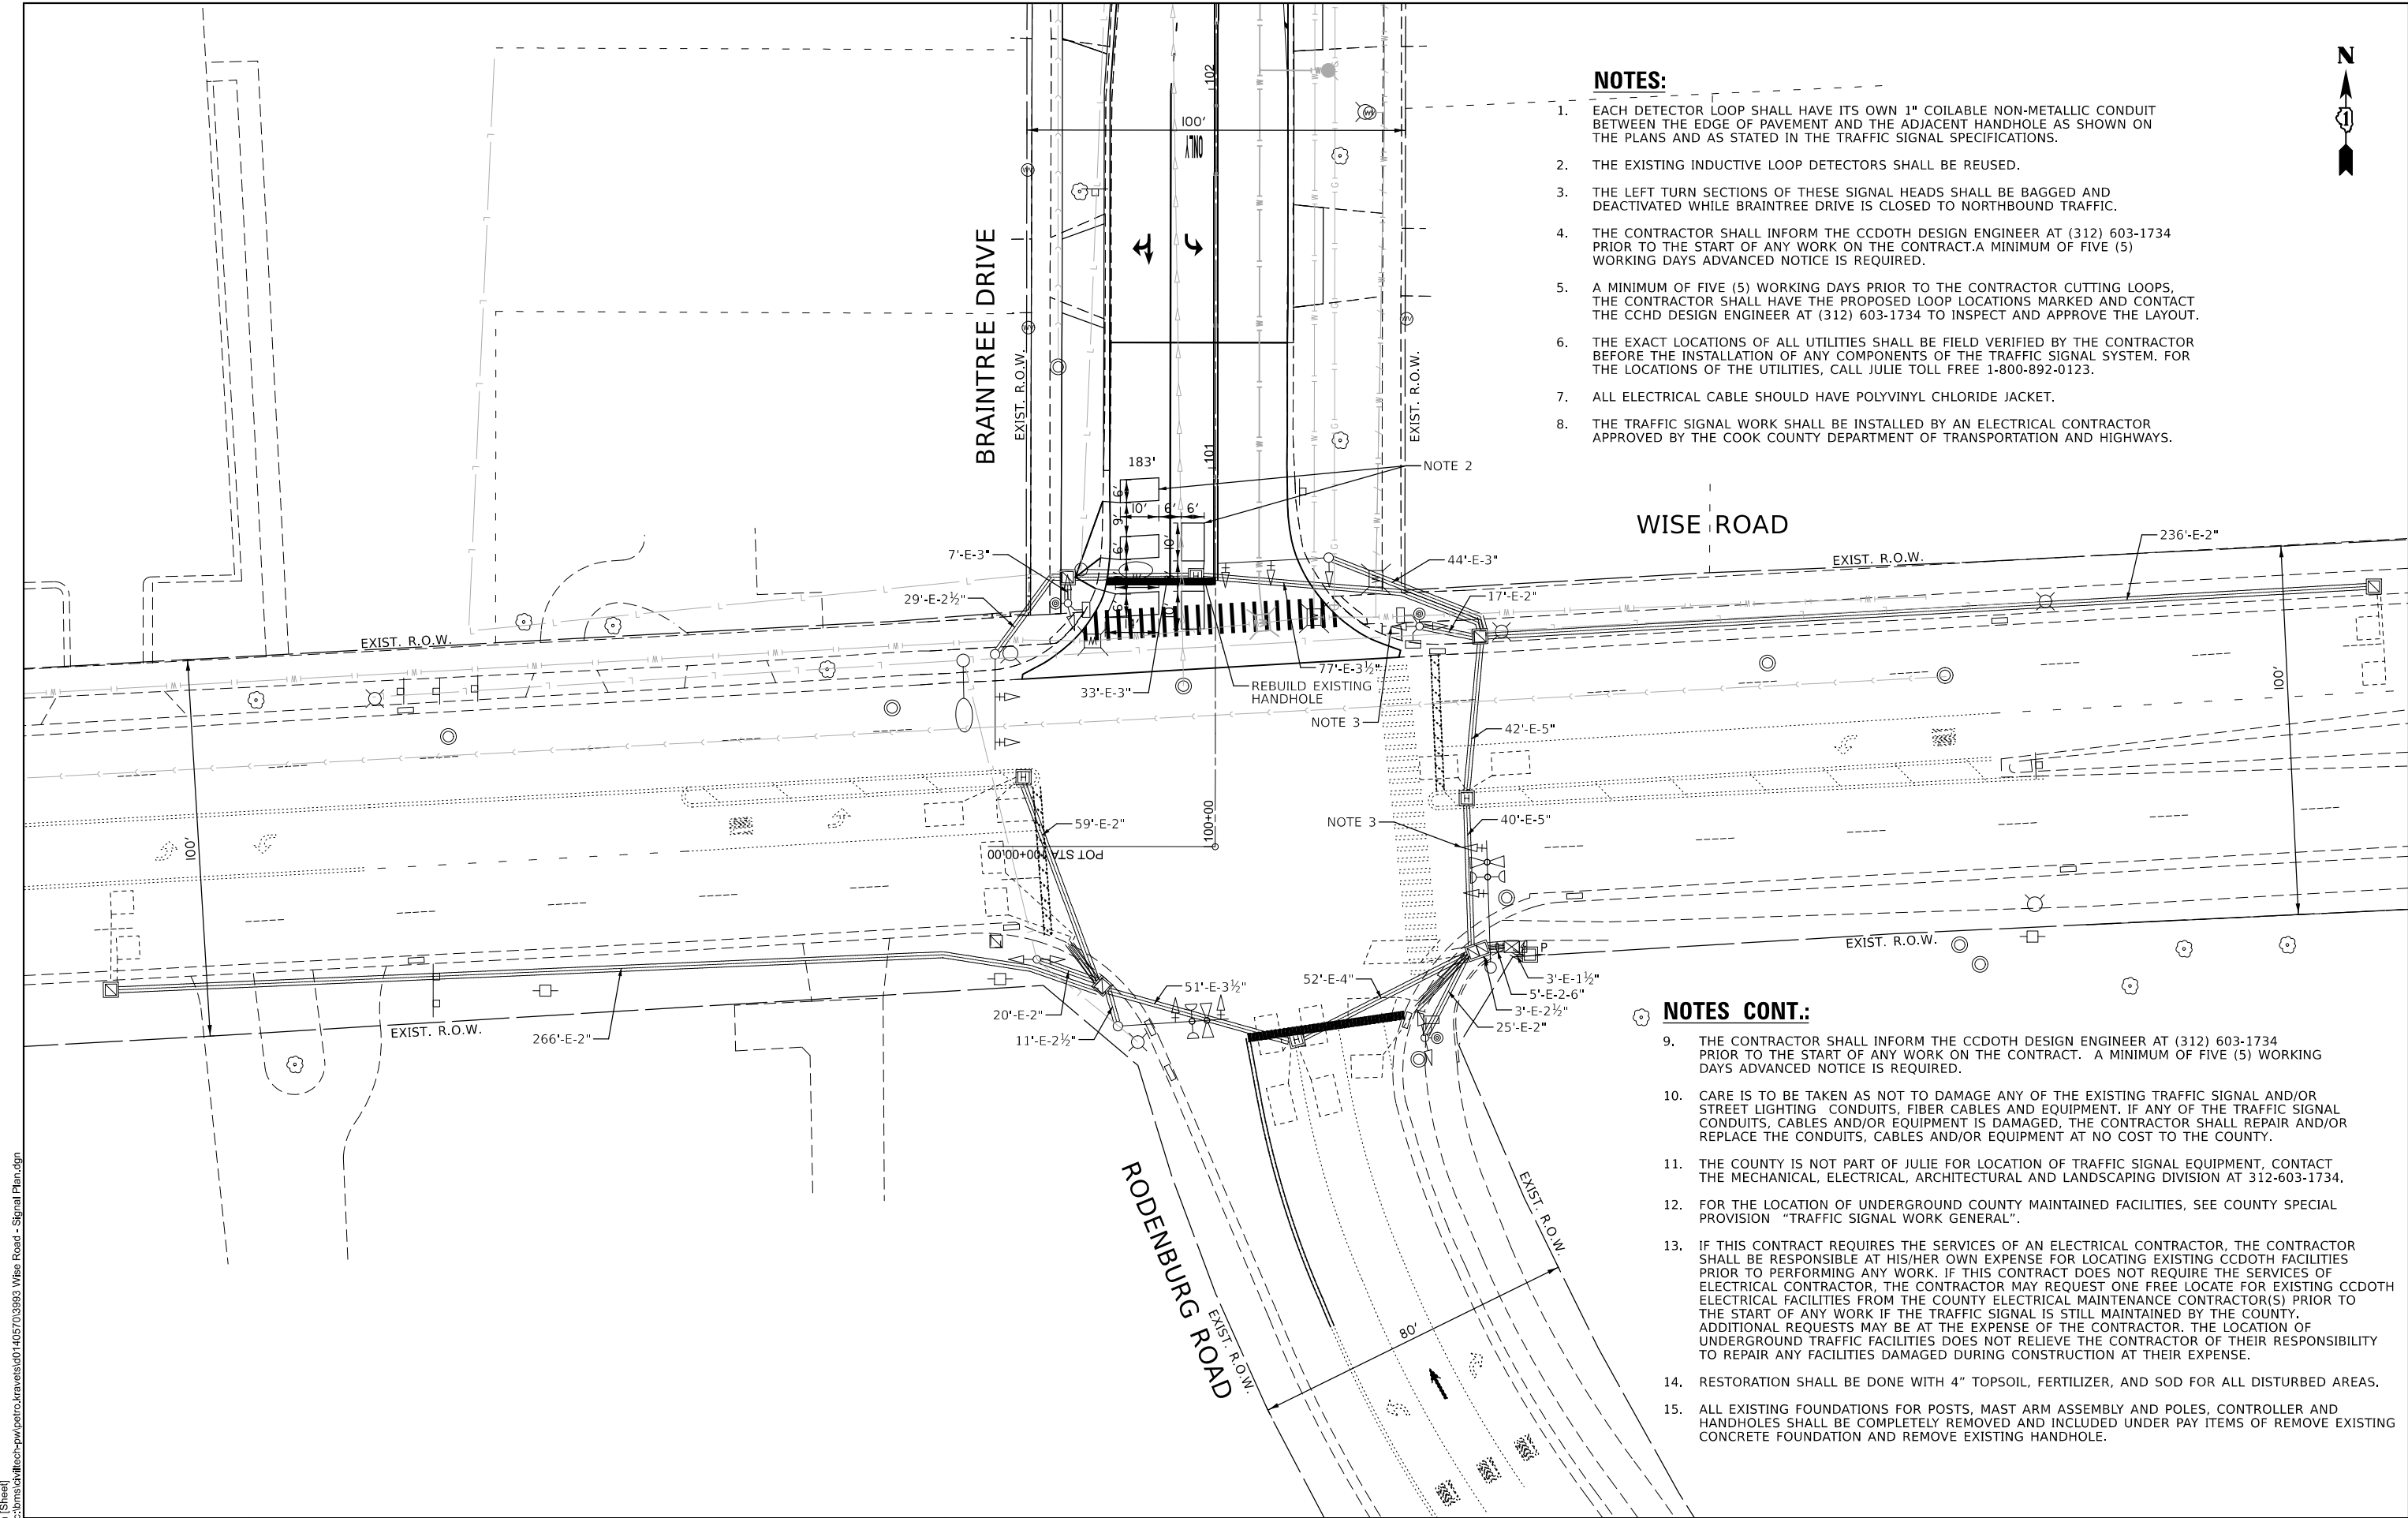

NOTES:

1. EACH DETECTOR LOOP SHALL HAVE ITS OWN 1" COILABLE NON-METALLIC CONDUIT BETWEEN THE EDGE OF PAVEMENT AND THE ADJACENT HANDHOLE AS SHOWN ON THE PLANS AND AS STATED IN THE TRAFFIC SIGNAL SPECIFICATIONS.
2. THE EXISTING INDUCTIVE LOOP DETECTORS SHALL BE REUSED.
3. THE LEFT TURN SECTIONS OF THESE SIGNAL HEADS SHALL BE BAGGED AND DEACTIVATED WHILE BRAINTREE DRIVE IS CLOSED TO NORTHBOUND TRAFFIC.
4. THE CONTRACTOR SHALL INFORM THE CCDOTH DESIGN ENGINEER AT (312) 603-1734 PRIOR TO THE START OF ANY WORK ON THE CONTRACT.A MINIMUM OF FIVE (5) WORKING DAYS ADVANCED NOTICE IS REQUIRED.
5. A MINIMUM OF FIVE (5) WORKING DAYS PRIOR TO THE CONTRACTOR CUTTING LOOPS, THE CONTRACTOR SHALL HAVE THE PROPOSED LOOP LOCATIONS MARKED AND CONTACT THE CCHD DESIGN ENGINEER AT (312) 603-1734 TO INSPECT AND APPROVE THE LAYOUT.
6. THE EXACT LOCATIONS OF ALL UTILITIES SHALL BE FIELD VERIFIED BY THE CONTRACTOR BEFORE THE INSTALLATION OF ANY COMPONENTS OF THE TRAFFIC SIGNAL SYSTEM. FOR THE LOCATIONS OF THE UTILITIES, CALL JULIE TOLL FREE 1-800-892-0123.
7. ALL ELECTRICAL CABLE SHOULD HAVE POLYVINYL CHLORIDE JACKET.
8. THE TRAFFIC SIGNAL WORK SHALL BE INSTALLED BY AN ELECTRICAL CONTRACTOR APPROVED BY THE COOK COUNTY DEPARTMENT OF TRANSPORTATION AND HIGHWAYS.

NOTES CONT.:

9. THE CONTRACTOR SHALL INFORM THE CCDOTH DESIGN ENGINEER AT (312) 603-1734 PRIOR TO THE START OF ANY WORK ON THE CONTRACT. A MINIMUM OF FIVE (5) WORKING DAYS ADVANCED NOTICE IS REQUIRED.
10. CARE IS TO BE TAKEN AS NOT TO DAMAGE ANY OF THE EXISTING TRAFFIC SIGNAL AND/OR STREET LIGHTING CONDUITS, FIBER CABLES AND EQUIPMENT. IF ANY OF THE TRAFFIC SIGNAL CONDUITS, CABLES AND/OR EQUIPMENT IS DAMAGED, THE CONTRACTOR SHALL REPAIR AND/OR REPLACE THE CONDUITS, CABLES AND/OR EQUIPMENT AT NO COST TO THE COUNTY.
11. THE COUNTY IS NOT PART OF JULIE FOR LOCATION OF TRAFFIC SIGNAL EQUIPMENT, CONTACT THE MECHANICAL, ELECTRICAL, ARCHITECTURAL AND LANDSCAPING DIVISION AT 312-603-1734.
12. FOR THE LOCATION OF UNDERGROUND COUNTY MAINTAINED FACILITIES, SEE COUNTY SPECIAL PROVISION "TRAFFIC SIGNAL WORK GENERAL".
13. IF THIS CONTRACT REQUIRES THE SERVICES OF AN ELECTRICAL CONTRACTOR, THE CONTRACTOR SHALL BE RESPONSIBLE AT HIS/HER OWN EXPENSE FOR LOCATING EXISTING CCDOTH FACILITIES PRIOR TO PERFORMING ANY WORK. IF THIS CONTRACT DOES NOT REQUIRE THE SERVICES OF ELECTRICAL CONTRACTOR, THE CONTRACTOR MAY REQUEST ONE FREE LOCATE FOR EXISTING CCDOTH ELECTRICAL FACILITIES FROM THE COUNTY ELECTRICAL MAINTENANCE CONTRACTOR(S) PRIOR TO THE START OF ANY WORK IF THE TRAFFIC SIGNAL IS STILL MAINTAINED BY THE COUNTY. ADDITIONAL REQUESTS MAY BE AT THE EXPENSE OF THE CONTRACTOR. THE LOCATION OF UNDERGROUND TRAFFIC FACILITIES DOES NOT RELIEVE THE CONTRACTOR OF THEIR RESPONSIBILITY TO REPAIR ANY FACILITIES DAMAGED DURING CONSTRUCTION AT THEIR EXPENSE.
14. RESTORATION SHALL BE DONE WITH 4" TOPSOIL, FERTILIZER, AND SOD FOR ALL DISTURBED AREAS.
15. ALL EXISTING FOUNDATIONS FOR POSTS, MAST ARM ASSEMBLY AND POLES, CONTROLLER AND HANDHOLES SHALL BE COMPLETELY REMOVED AND INCLUDED UNDER PAY ITEMS OF REMOVE EXISTING CONCRETE FOUNDATION AND REMOVE EXISTING HANDHOLE.

PLOT DATE = 12/11/2025	USER NAME = pk	DESIGNED - LEP	REVISED -
		DRAWN - LEP	REVISED -
		CHECKED - JJE	REVISED -
	DATE - 12/12/2025		REVISED -

STATE OF ILLINOIS
DEPARTMENT OF TRANSPORTATION


**TRAFFIC SIGNAL MODERNIZATION PLAN
BRAINTREE DRIVE AND WISE ROAD**

SCALE: SHEET 1 OF 1 SHEETS STA. TO STA.


MUN RTE.	SECTION	COUNTY	TOTAL SHEETS	SHEET NO.
4029	23-00146-00-PV	COOK	315	168
CONTRACT NO. 61M26				
ILLINOIS FED. AID PROJECT				

MODEL: CablePlan-1 [Sheet]
FILE NAME: c:\bms\dwf\tech-pw\patco.kravets\014057033933 Wise Road - Cable Plan.dgn


EXISTING CONTROLLER SEQUENCE

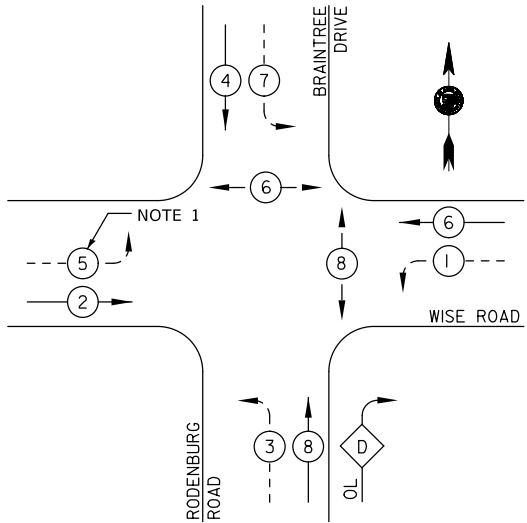

EXISTING EMERGENCY VEHICLE PREEMPTION SEQUENCE

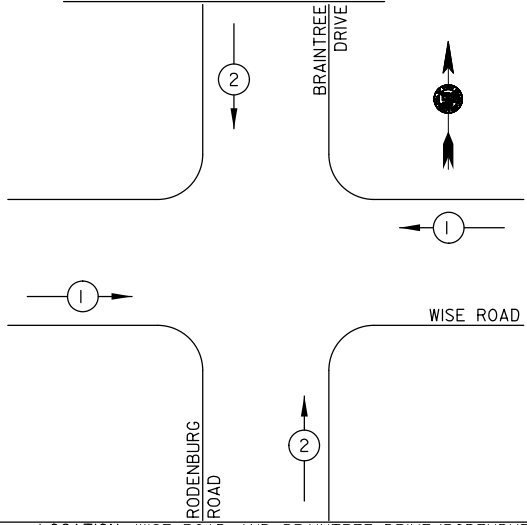

LEGEND

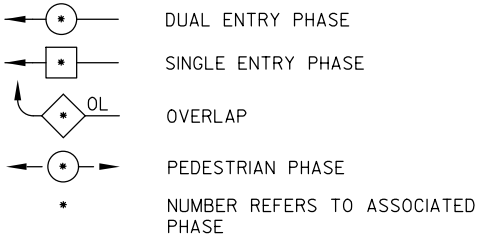

RIGHT TURN OVERLAP

PHASE DESIGNATION:

$$\text{OVERLAP LETTER} = \frac{\text{PERMISSIVE PHASE}}{8} + \frac{\text{PROTECTED PHASE}}{1}$$

PROPOSED EMERGENCY VEHICLE PREEMPTORS		
EMERGENCY VEHICLE PREEMPTOR	1	2
MOVEMENT		

NOTES:

- THE LEFT TURN SECTIONS OF THESE SIGNAL HEADS SHALL BE BAGGED AND DEACTIVATED WHILE BRAINTREE DRIVE IS CLOSED TO NORTHBOUND TRAFFIC.

SCHEDULE OF QUANTITIES


PAY ITEM	UNIT	QNTY.
MAINTENANCE OF EXISTING TRAFFIC SIGNAL INSTALLATION	EACH	1
ELECTRIC CABLE IN CONDUIT, LEAD-IN, NO. 14 1PAIR	FOOT	442
DETECTOR LOOP, TYPE I	FOOT	183
REMOVE ELECTRIC CABLE FROM CONDUIT	FOOT	442
REBUILD EXISTING HEAVY-DUTY HANDHOLE	EACH	1
TEMPORARY TRAFFIC SIGNAL TIMING	EACH	6

NOTE:

THE PAY ITEM "TEMPORARY TRAFFIC SIGNAL TIMING" SHALL BE INCLUDED AT THE INTERSECTIONS OF WISE ROAD/BRAINTREE DRIVE, WISE ROAD/SPRINGSGUTH ROAD, SCHAUMBURG ROAD/SPRINGSGUTH ROAD, SCHAUMBURG ROAD/BRAINTREE DRIVE, SCHAUMBURG ROAD/GRAND CENTRAL LANE AND SCHAUMBURG ROAD/SALEM DRIVE.

CABLE PLAN

(NOT TO SCALE)

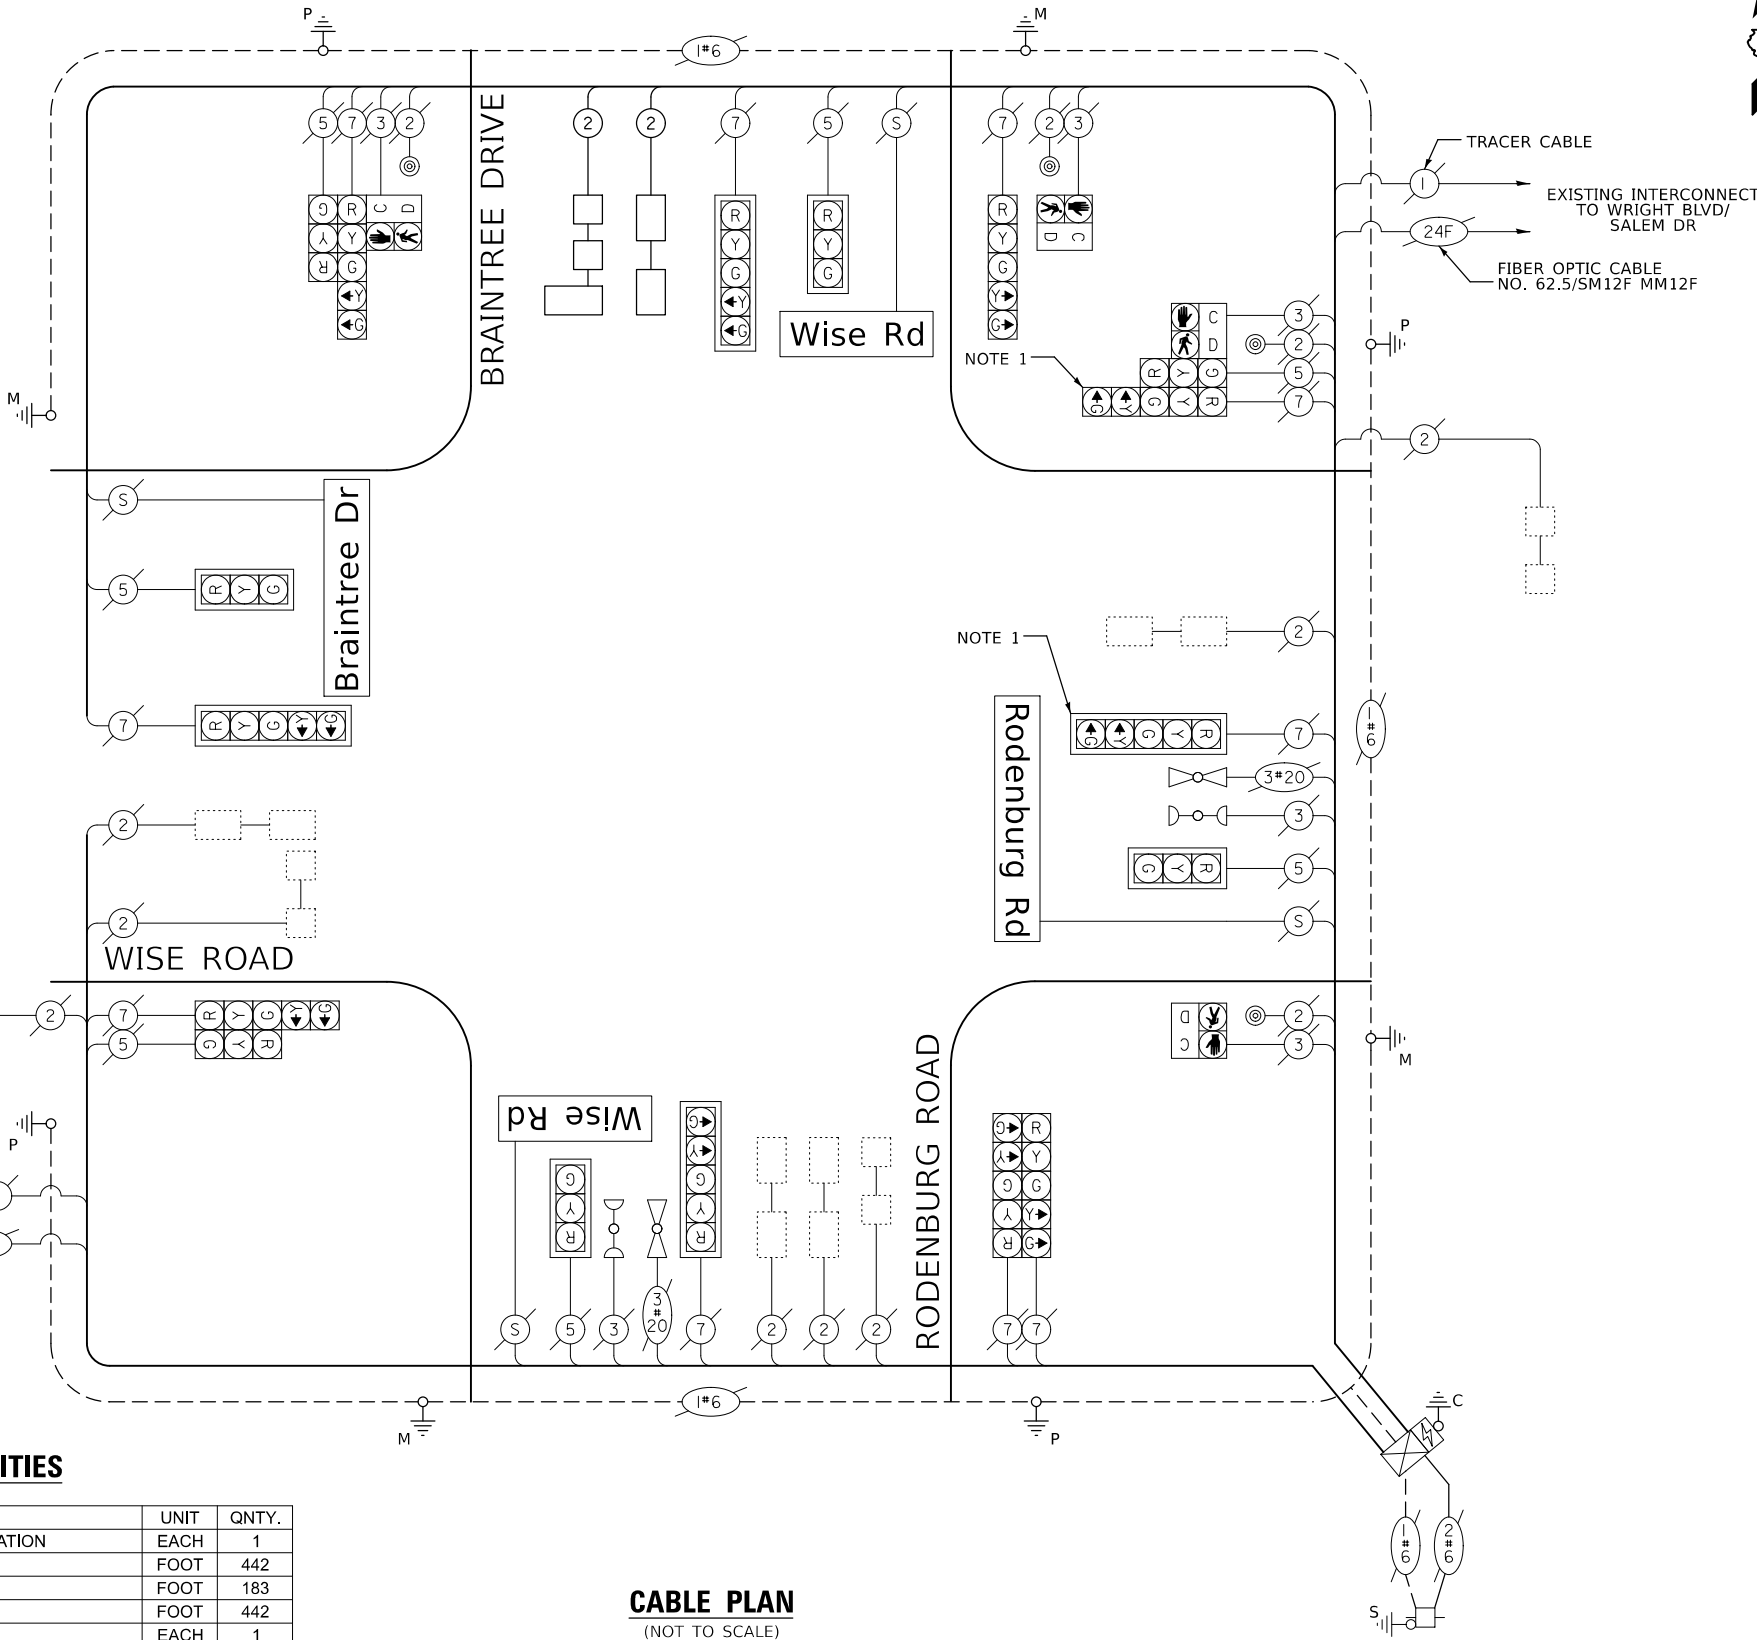

LOCATION: WISE ROAD AND BRAINTREE DRIVE/RODENBURG ROAD

COOK COUNTY

DEPARTMENT OF TRANSPORTATION AND HIGHWAYS

TRAFFIC SIGNAL INSTALLATION

ELECTRICAL SERVICE REQUIREMENTS

TYPE	NO. LAMPS	WATTAGE	% OPERATION	TOTAL
CONTROLLER	1	100	1.00	100.0
VEHICLE DET.	-	-	-	-
PED. SIGNAL	4	20	1.00	80.0
12" SIGNAL (RED)	17	11	0.50	93.5
(YELLOW)	17	20	0.05	17.0
(GREEN)	17	12	0.45	91.8
(ARROW)	10	10	0.10	10.0
ILLUMINATED LED STREET NAME SIGN	4	120	0.50	240.0
TOTAL =				632.3

ENERGY COST TO:

COOK COUNTY BUREAU OF ADMINISTRATION
118 N. CLARK STREET, ROOM 801
CHICAGO, IL 60602
TOWER ACCOUNT NO. -----

ENERGY COST SHARE:

COOK COUNTY: 100%

ENERGY SUPPLY CONTACT: COM ED
PHONE: (866) 639-3532
COMPANY: COM ED

STATE OF ILLINOIS
DEPARTMENT OF TRANSPORTATION


PROPOSED CABLE PLAN, PHASE DESIGNATION DIAGRAM, EMERGENCY
VEHICLE PREEMPTION SEQUENCE, AND SCHEDULE OF QUANTITIES
BRAINTREE DRIVE AND WISE ROAD

SCALE: SHEET 1 OF 1 SHEETS STA. TO STA.

MUN RTE.	SECTION	COUNTY	TOTAL SHEETS	SHEET NO.
4029	23-00146-00-PV	COOK	313	169
CONTRACT NO. 61M26				

ILLINOIS FED. AID PROJECT

 MODEL: 3993-0201- Plan 0 [Sheet]
FILE NAME: c:\bms\chilich-pw\patro.kravets\0140571\3993-0201-shH-lighting_01.dgn



EXISTING LIGHTING UNIT



REMOVAL OF LIGHTING UNIT, SALVAGE



EXISTING LIGHTING UNIT
(WEATHERSFIELD WAY)



PROPOSED LIGHTING UNIT
LUMINAIRE, LED, SPECIAL (120V)
LIGHT POLE , ALUMINUM
25 FT. M.H 10FT. MAST ARM
LIGHT POLE FOUNDATION, METAL
11 1/2" BOLT CIRCLE, 8 5/8" X 6"
BREAKAWAY DEVICE, TRANSFORMER BASE
11.5 INCH BOLT CIRCLE (ONLY AS
SPECIFIED IN PLANS)



RELOCATED EXISTING LIGHTING UNIT



 
PROPOSED UNIT DUCT
(AS SPECIFIED IN PLANS)



PROPOSED UNDERGROUND CONDUIT, GALVANIZED STEEL
(SIZE AS SPECIFIED IN PLANS)



EXISTING LIGHTING CABLES



REMOVE ELECTRIC CABLE FROM CONDUIT

LIGHTING GENERAL NOTES

1. IT SHALL BE THE CONTRACTOR'S RESPONSIBILITY TO VERIFY ALL DIMENSIONS AND CONDITIONS IN THE FIELD PRIOR TO ORDERING MATERIALS AND BEGINNING CONSTRUCTION.
2. PAY ITEMS IN THE SUMMARY OF QUANTITIES HAVE BEEN ESTIMATED. IF, IN THE ENGINEER'S OPINION, ANY WORK IS NOT REQUIRED, THAT ITEM WILL BE DEDUCTED FROM THE CONTRACT AND NO ADDITIONAL COMPENSATION WILL BE ALLOWED.
3. IT SHALL BE THE CONTRACTOR'S RESPONSIBILITY TO MARK THE PROPOSED LOCATIONS OF ALL LIGHT POLES FOR EXAMINATION AND CONFIRMATION WITH THE RESIDENT ENGINEER.
4. THE CONTRACTOR SHALL VERIFY ALL UTILITY LOCATIONS PRIOR TO AUGURING FOR LIGHT POLE FOUNDATIONS. THE EXACT LOCATIONS FOR ALL ITEMS SHALL BE CONFIRMED WITH THE RESIDENT ENGINEER.
5. THE CONTRACTOR SHALL BE RESPONSIBLE FOR THE ESTABLISHMENT OF FINISHED GRADE. THE RESIDENT ENGINEER MAY ASSIST THE CONTRACTOR, AS APPLICABLE, BUT THE RESPONSIBILITY FOR COORDINATING THE FINISHED GRADE ELEVATION WITH THE TOP OF FOUNDATIONS HEIGHTS AND THE LIGHT SHALL REMAIN WITH THE CONTRACTOR.
6. LIGHT POLE FOUNDATION TYPE WILL BE METAL UNLESS OTHERWISE SPECIFIED IN THE PLANS. FOUNDATION TYPE IS BASED ON KNOWN UTILITY INFORMATION. OFFSET FOUNDATION WILL BE USED IF UTILITY CONFLICT IS UNAVOIDABLE. FOUNDATION TYPE SHALL BE APPROVED BY THE ENGINEER PRIOR TO INSTALLATION. CONTRACTOR WILL BE PAID FOR THE FOUNDATION TYPE INSTALLED WITH NO ADDITIONAL COMPENSATION FOR CHANGE FROM CONTRACT PLAN.
7. FOR ALL CONCRETE FOUNDATIONS, A MINIMUM OF 2 SLEEVES SHALL BE PROVIDED REGARDLESS OF WHAT IS BEING INSTALLED. THE SLEEVES SHALL BE SEALED AND CAPPED TO PREVENT MOISTURE OR CONTAMINANTS. MATERIAL AND LABOR WILL NOT BE PAID FOR SEPARATELY BUT WILL BE INCLUDED IN THE PAY ITEM FOR LIGHT POLE FOUNDATION.
8. TO MAINTAIN THE STRUCTURAL INTEGRITY OF ALUMINUM POLES WITH MAST ARMS, THEY SHALL NOT BE ERECTED AND LEFT TO STAND WITHOUT LUMINAIRES. NOTE THAT THE CONTRACTOR SHALL NOT BE PAID FOR POLES UNTIL LUMINAIRES ARE INSTALLED.
9. CONDUIT AND UNIT DUCT MUST BE POSITIONED IN THE FIELD TO AVOID CONFLICT WITH TREES, BUSHES, DRAINS, OTHER UTILITIES, AND LANDSCAPING. PREFERRED LOCATION OF UNIT DUCT IS 12 INCHES OFF PROPOSED BACK OF CURB AND IN NO CASE SHALL IT BE CLOSER THEN 12 INCHES. PLACEMENT OF UNIT DUCT GREATER THAN 12 INCHES FROM THE BACK OF CURB SHALL BE APPROVED BY THE ENGINEER.
10. WHEN SPLICING TO EXISTING POLE, ANY AND ALL WORK REQUIRED TO RUN THE PROPOSED UNIT DUCT INTO EXISTING FOUNDATION SLEEVE AND SPLICING IN EXISTING POLE SHALL BE COVERED AND INCLUDED IN THE PAY ITEM FOR THE UNIT DUCT.
11. THE CABLE TRENCH SHALL BE BACKFILLED AND FIRMLY COMPACTED BEFORE ANY LIGHT STANDARD IS ERECTED.
12. THE INSTALLATION OF BURIED WARNING TAPE SHALL BE INSPECTED AND APPROVED BY THE RESIDENT ENGINEER.
13. NO UNDERGROUND SPLICING ALLOWED.
14. ANY DAMAGE TO PAVEMENT, SIDEWALK, CURB, OR ANY OTHER PORTION OF THE ROADWAY NOT SPECIFICALLY TO BE REMOVED AND REPLACED SHALL BE REPAIRED OR REPLACED BY THE CONTRACTOR AT NO ADDITIONAL COST AND REPLACEMENT SHALL MEET THE APPROVAL OF THE ENGINEER.
15. OFFSETS CALL-OFFS FOR LIGHT POLES ARE FROM THE CENTER OF POLES TO CONSTRUCTION CENTERLINE
16. EXISTING LIGHTING UNIT TO BE RELOCATED WILL BE COORDINATED AND COMPLETED ON THE SAME DAY WITHOUT ANY INTERRUPTION OF OPERATION FOR THAT SAME EVENING.
17. IF THE PROPOSED ROUNDABOUT WILL BE READY TO BE OPEN TO TRAFFIC PRIOR TO THE LIGHTING SYSTEM BEING OPERATIONAL (BECAUSE OF DELAYS IN OBTAINING LUMINAIRES, POLES, FOUNDATIONS, UNIT DUCT OR OTHER LIGHTING ITEMS) THEN TEMPORARY LIGHTING UNITS AND AERIAL CABLES SHALL BE INSTALLED SO THE ROADWAY CAN BE OPENED TO TRAFFIC. THE WORK SHALL BE COORDINATED AND APPROVED BY THE ENGINEER AND GENERAL CONTRACTOR.

A. THE LOCATION OF TEMPORARY POLES SHALL BE NEAR PROPOSED LOCATIONS BUT SHALL NOT INTERFER WITH INSTALLATION OF PROPOSED POLE LOCATIONS



B. THE MOUNTING HEIGHT OF THE LUMINAIRE SHALL BE THE SAME AS ON THE PROPOSED LIGHT POLES.

C. WHEN TRANSFERRING THE LIGHTING FROM THE TEMPORARY POLES TO THE PROPOSED POLES, THE TRANSFER SHALL BE SEQUENCED SO THAT BY EVENING EACH NIGHT THE ROADWAY AND INTERSECTIONS ARE COMPLETELY LIT BY EITHER TEMPORARY, PROPOSED OR A COMBINATION OF BOTH.

LIGHTING SCHEDULE OF QUANTITIES

CODED PAY ITEM NO.	ITEM	UNIT	TOTAL QUANTITY
80400200	ELECTRIC UTILITY SERVICE CONNECTION	L SUM	1
81028240	UNDERGROUND CONDUIT, GALVANIZED STEEL, 4" DIA.	FOOT	1075
81028730	UNDERGROUND CONDUIT, COILABLE NONMETALLIC CONDUIT, 1 1/4" DIA.	FOOT	2921
81603080	UNIT DUCT, 600V, 3-1C NO. 2, 1/C NO. 4 GROUND, (XLP-TYPE USE), 1 1/4" POLYETHYLENE	FOOT	804
81702130	ELECTRIC CABLE IN CONDUIT, 600V (XLP-TYPE USE) 1/C NO. 6	FOOT	5842
81800230	AERIAL CABLE, 2-1/C NO. 6 WITH MESSENGER WIRE	FOOT	1150
83000198	LIGHT POLE, ALUMINUM, 25FT. M.H. 10FT. MAST ARM	EACH	10
83600352	LIGHT POLE FOUNDATION, METAL, 11 1/2" BOLT CIRCLE, 8 5/8" X 6'	EACH	14
83800105	BREAKAWAY DEVICE, TRANSFORMER BASE, 11.5 INCH BOLT CIRCLE	EACH	8
84100110	REMOVAL OF TEMPORARY LIGHTING UNIT	EACH	11
84200500	REMOVAL OF LIGHTING UNIT, SALVAGE	EACH	4
84200804	REMOVAL OF POLE FOUNDATION	EACH	9
84400105	RELOCATE EXISTING LIGHTING UNIT	EACH	5
89502300	REMOVE ELECTRIC CABLE FROM CONDUIT	FOOT	6220
X1400238	LUMINAIRE, LED, SPECIAL	EACH	10
X8211004	TEMPORARY LUMINAIRE, LED, ROADWAY, OUTPUT DESIGNATION D	EACH	9
X8302141	TEMPORARY WOOD POLE, 40 FT., CLASS 4	EACH	11
X8360215	LIGHT POLE FOUNDATION, 24" DIAMETER, OFFSET	FOOT	12
X8772115	TEMPORARY MAST ARM, ALUMINUM, 15FT	EACH	9
X8000003	MAINTENANCE OF LIGHTING SYSTEM	CAL MO	16

	USER NAME = pk	DESIGNED - SJC	REVISED -	STATE OF ILLINOIS DEPARTMENT OF TRANSPORTATION	LIGHTING LEGEND, GENERAL NOTES, AND BILL OF MATERIAL				MUN RTE.	SECTION	COUNTY	TOTAL SHEETS	SHEET NO.
		DRAWN - SJC	REVISED -						4029	23-00146-00-PV	COOK	315	170
		CHECKED - DNM	REVISED -						CONTRACT NO. 61M26				
	PLOT DATE = 12/11/2025	DATE - 12/12/2025	REVISED -		SCALE: N.T.S.	SHEET 1	OF 1	SHEETS	STA. 129+00.00	TO STA. 159+00.00	ILLINOIS FED. AID PROJECT		

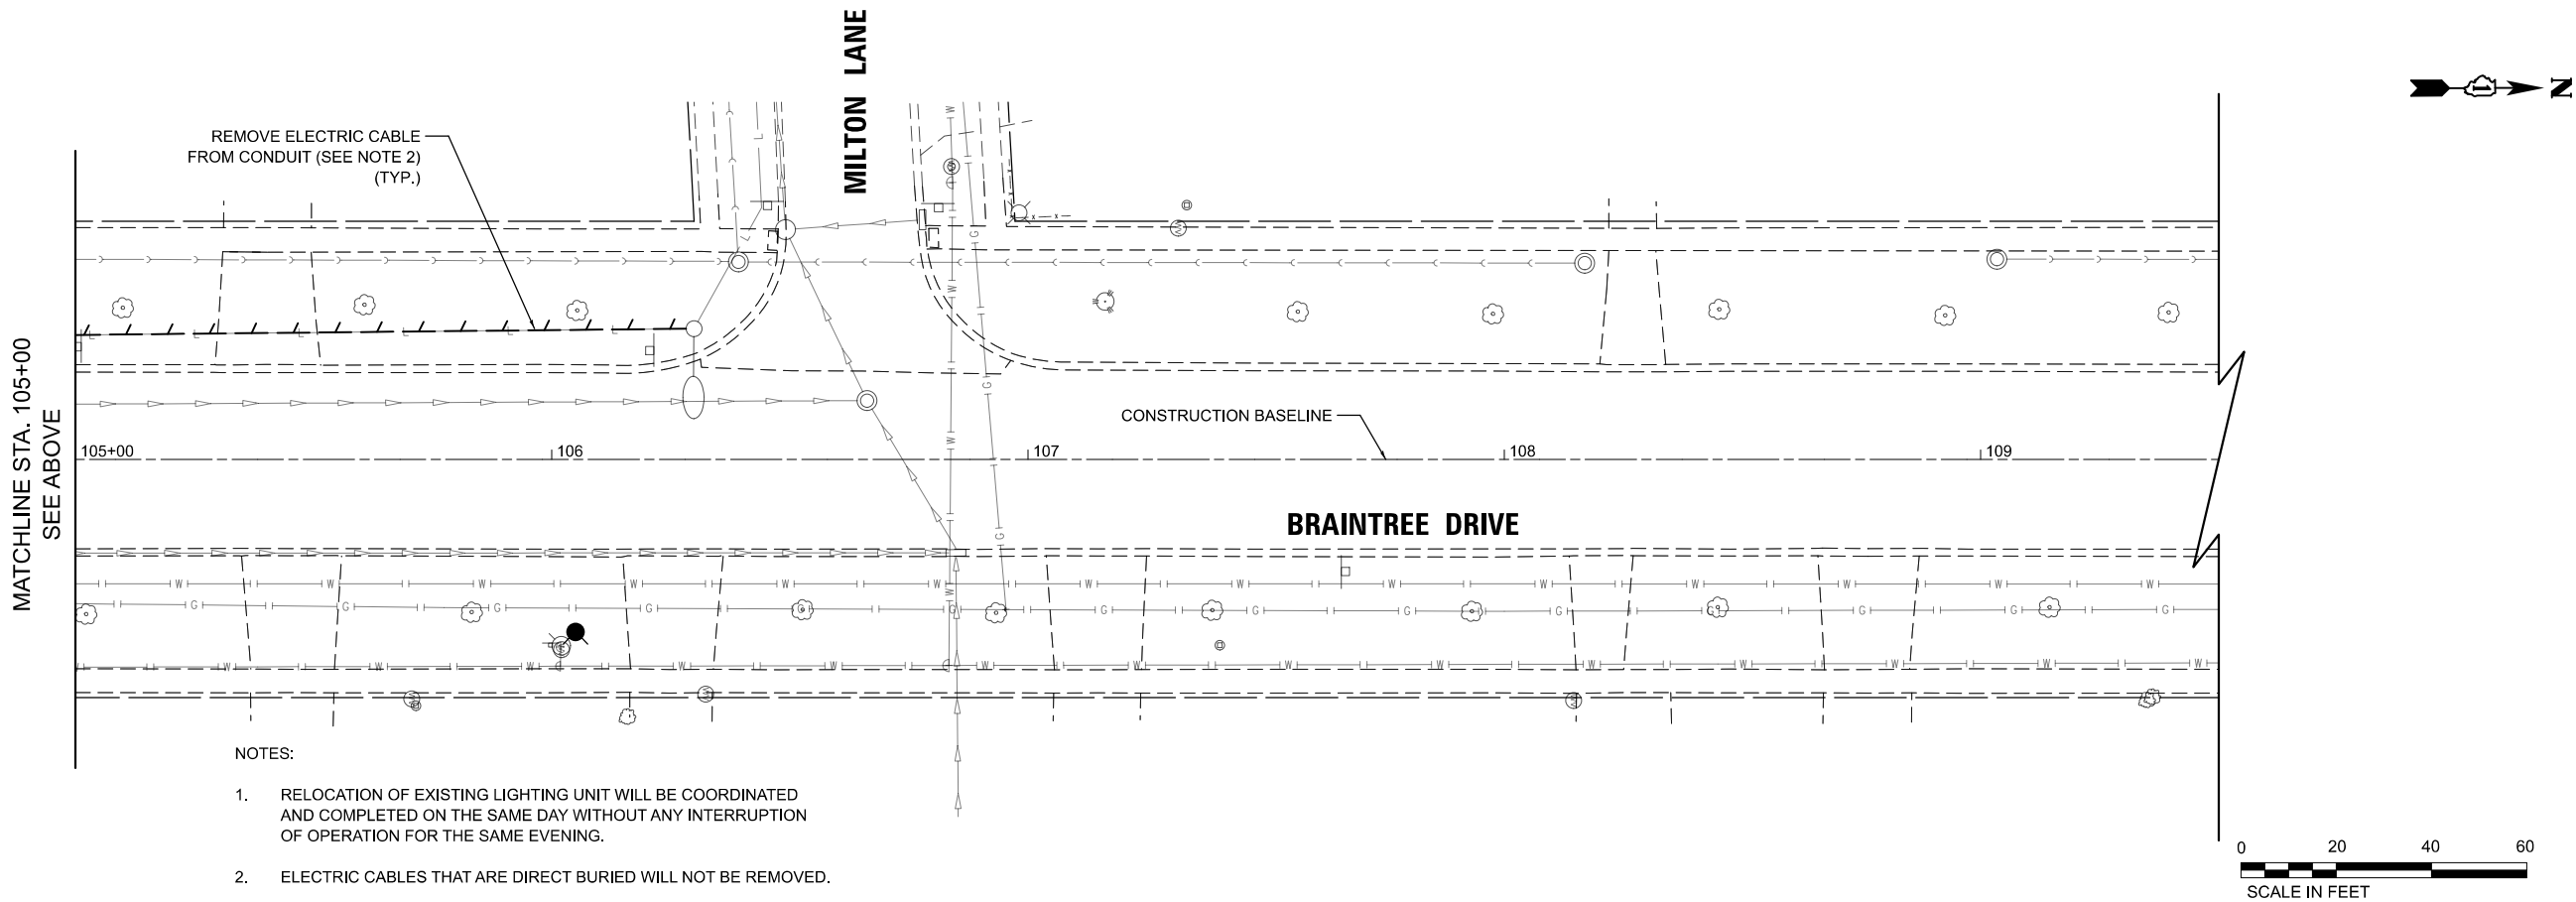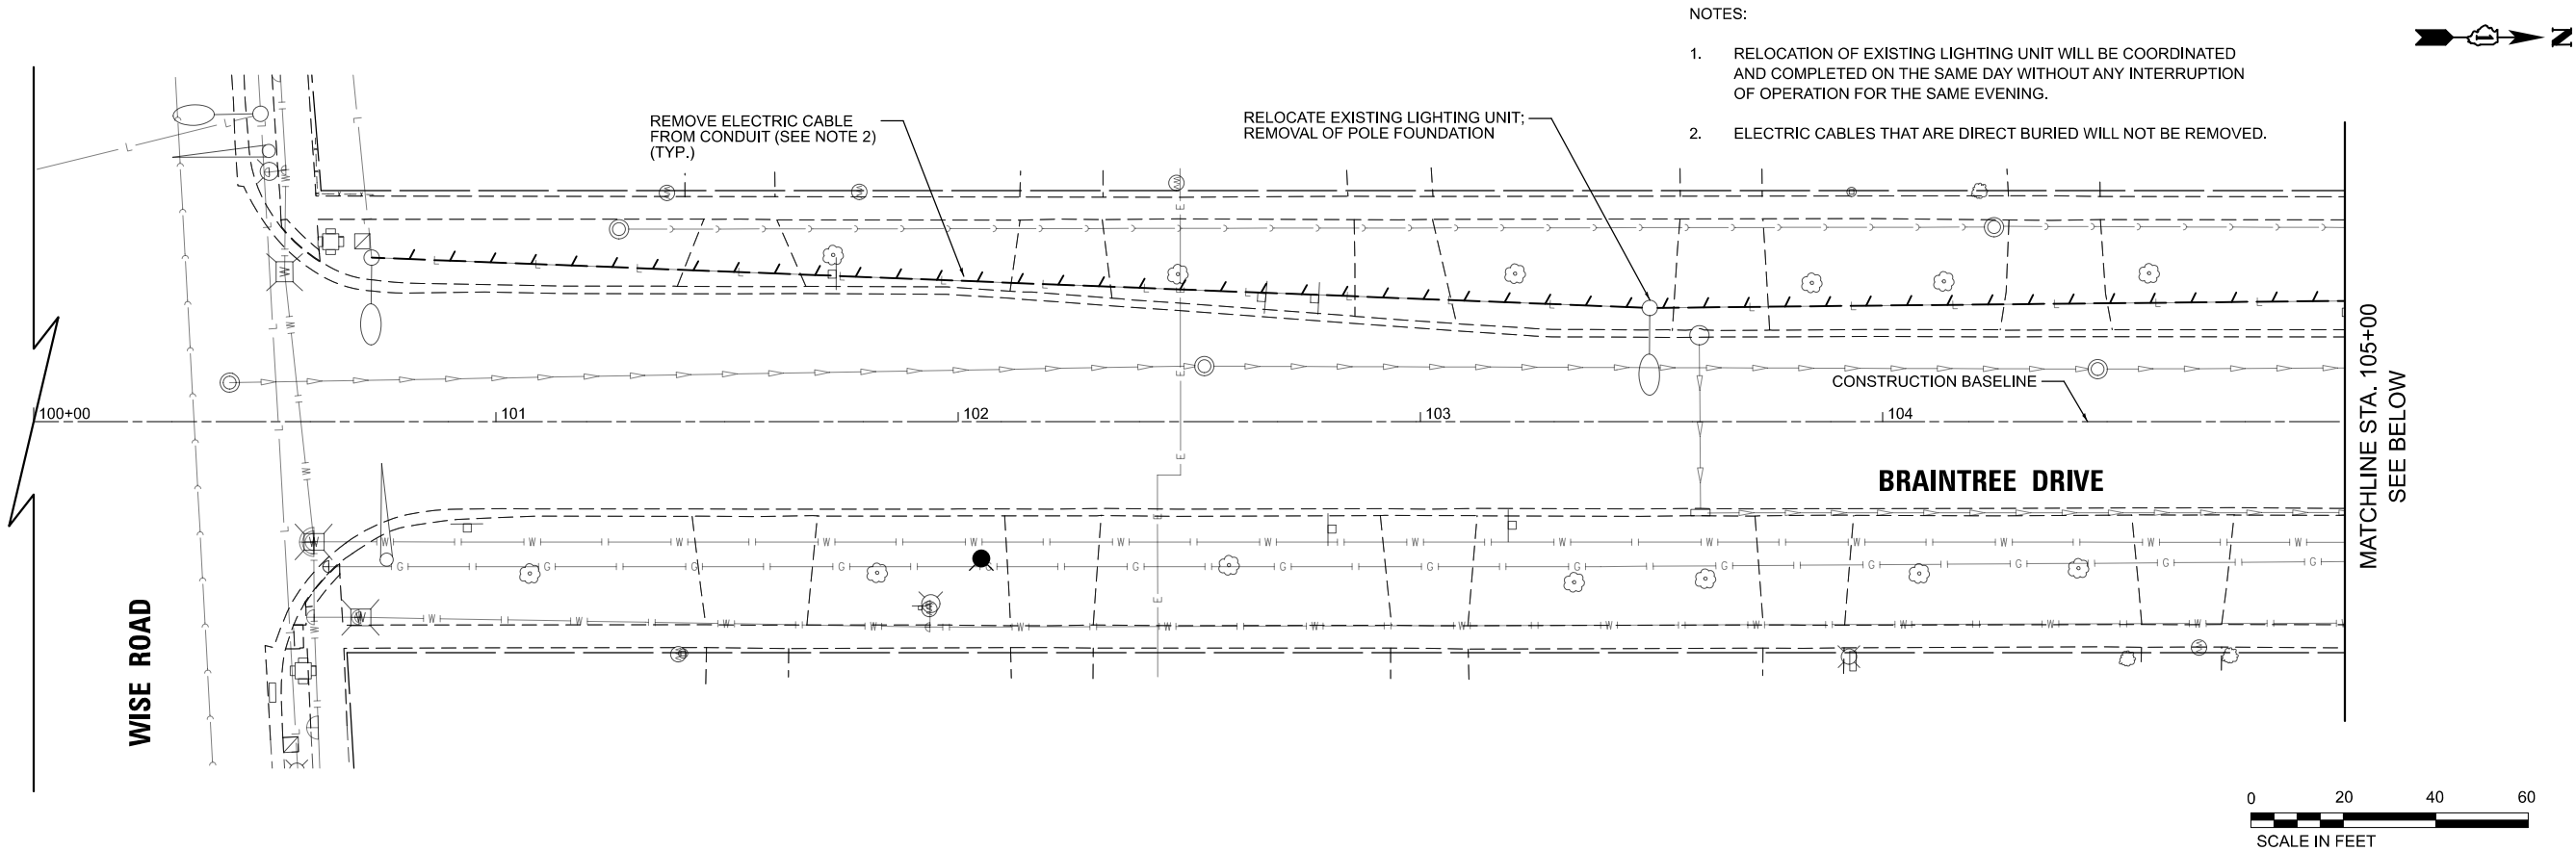

- NOTES:
1. RELOCATION OF EXISTING LIGHTING UNIT WILL BE COORDINATED AND COMPLETED ON THE SAME DAY WITHOUT ANY INTERRUPTION OF OPERATION FOR THE SAME EVENING.
 2. ELECTRIC CABLES THAT ARE DIRECT BURIED WILL NOT BE REMOVED.

MODEL: Braintree - Plan 0-1 [Sheet]
FILE NAME: c:\bms\stl\sch-pw\patro.kravets\01405713393-0201-shd-lighting 02-07.dgn


PLOT DATE	USER NAME = pk		DESIGNED -	SJC	REVISED -	
			DRAWN -	SJC	REVISED -	
			CHECKED -	DNM	REVISED -	
	DATE = 12/15/2025		DATE -	12/12/2025	REVISED -	

STATE OF ILLINOIS
DEPARTMENT OF TRANSPORTATION

BRAINTREE DRIVE
LIGHTING REMOVAL PLAN

SCALE: 1"=20' SHEET 1 OF 7 SHEETS STA. 100+00.00 TO STA. 105+00.00

MUN RTE.	SECTION	COUNTY	TOTAL SHEETS	SHEET NO.
4029	23-00146-00-PV	COOK	315	171
CONTRACT NO. 61M26				
ILLINOIS FED. AID PROJECT				


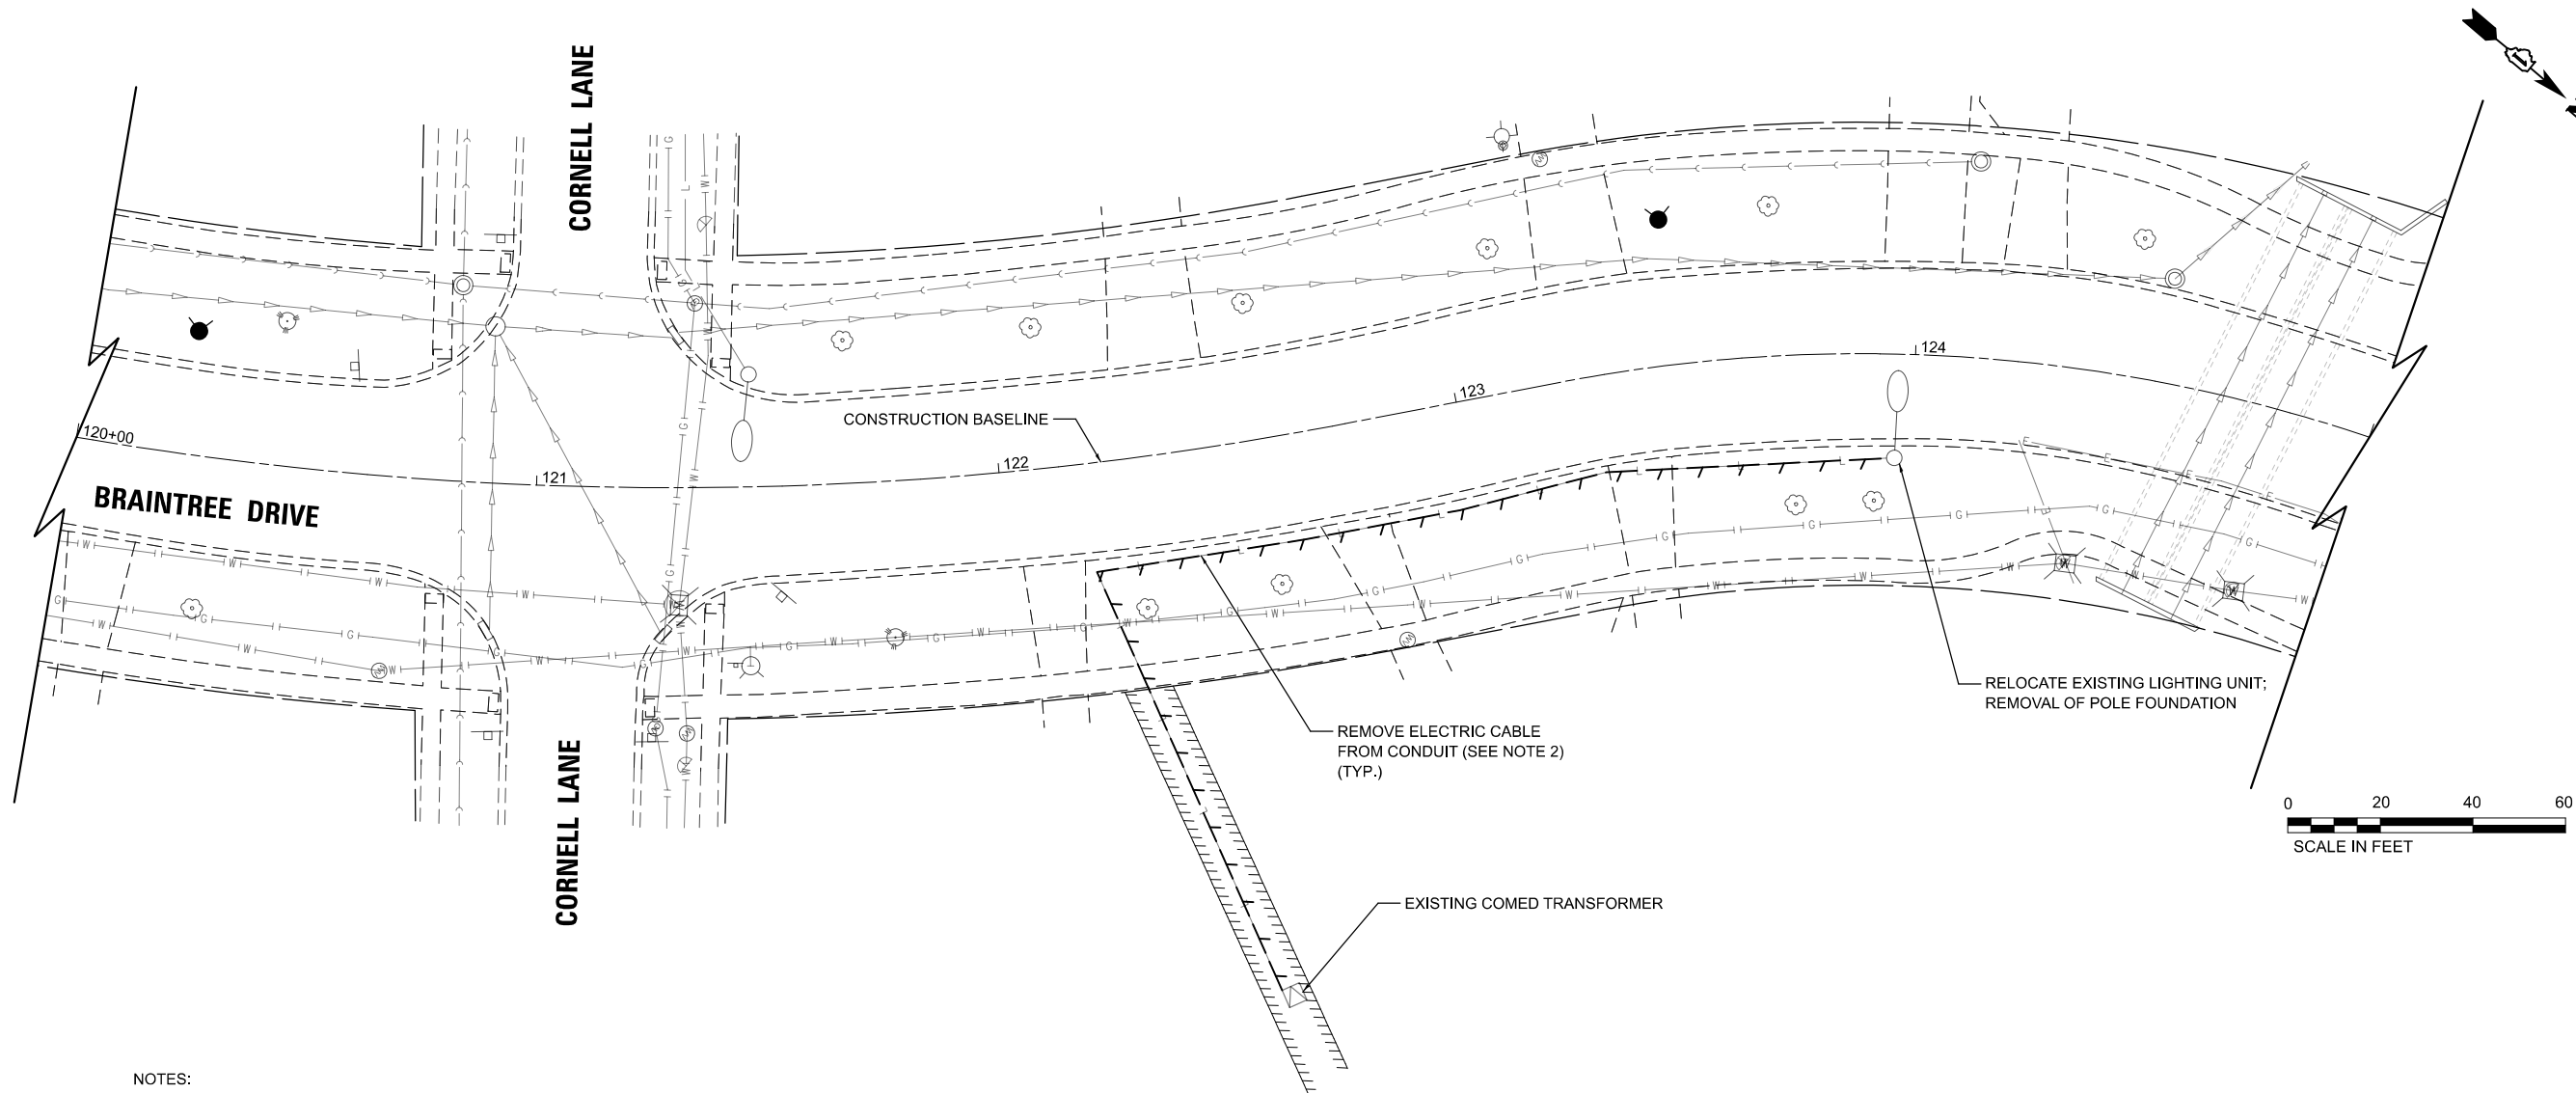


- NOTES:
- 1. RELOCATION OF EXISTING LIGHTING UNIT WILL BE COORDINATED AND COMPLETED ON THE SAME DAY WITHOUT ANY INTERRUPTION OF OPERATION FOR THE SAME EVENING.
 - 2. ELECTRIC CABLES THAT ARE DIRECT BURIED WILL NOT BE REMOVED.

MODEL: Braintree - Plan (A-3) [Sheet]
FILE NAME: c:\bms\stl\tech-pw\patro.kravets\dd140571\3993-0201-shd-lighting-02-07.dgn

	USER NAME = pk		DESIGNED - SJC	REVISED -	STATE OF ILLINOIS DEPARTMENT OF TRANSPORTATION	BRAINTREE DRIVE LIGHTING REMOVAL PLAN			MUN RTE.	SECTION	COUNTY	TOTAL SHEETS	SHEET NO.
			DRAWN - SJC	REVISED -					4029	23-00146-00-PV	COOK	315	172
			CHECKED - DNM	REVISED -		CONTRACT NO. 61M26							
	PLOT DATE = 12/11/2025		DATE - 12/12/2025	REVISED -		SCALE: 1"=20'	SHEET 2	OF 7 SHEETS	STA. 120+00.00	TO STA. 125+00.00	ILLINOIS FED. AID PROJECT		

MODEL: Braintree - Plan 1 [Sheet]
FILE NAME: c:\bms\sketch-pw\patco_kraves\dd1405713393-0201-shd-lighting 02-07.dgn

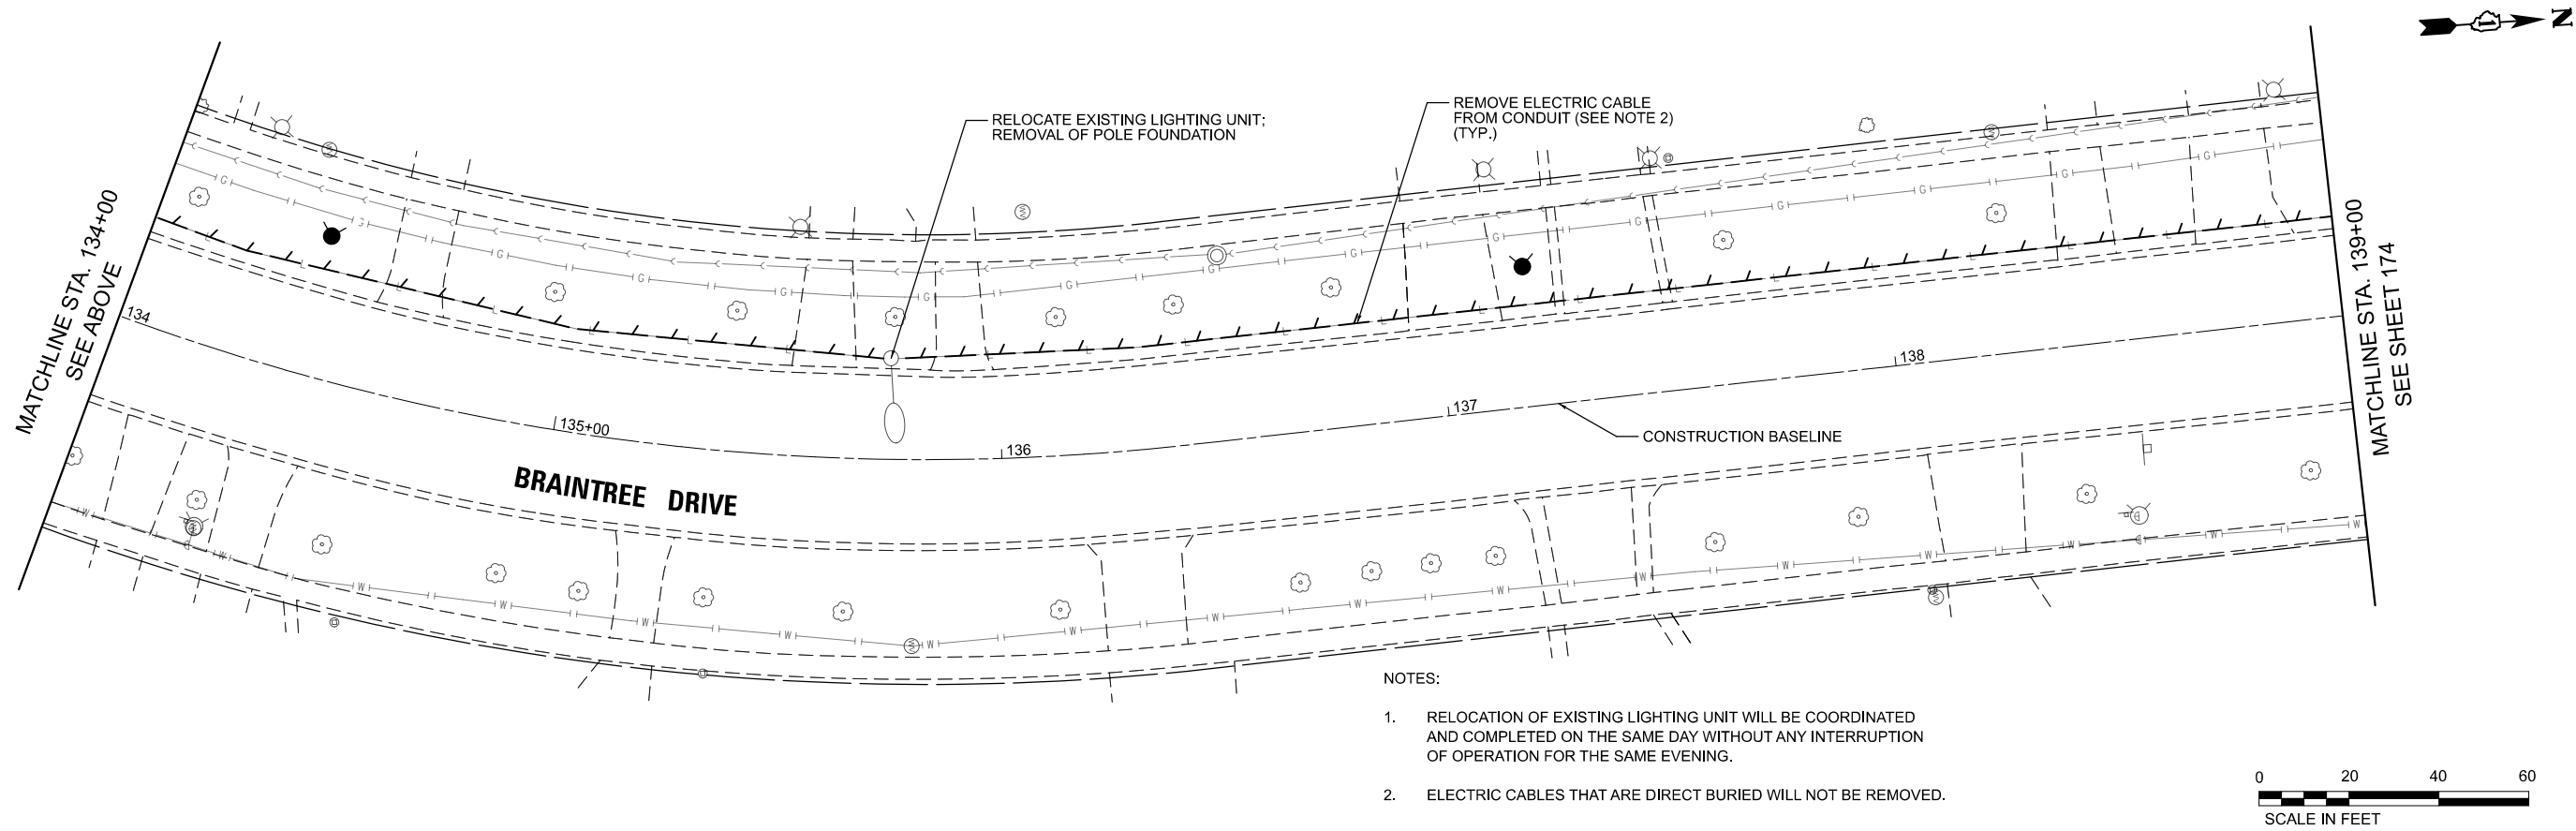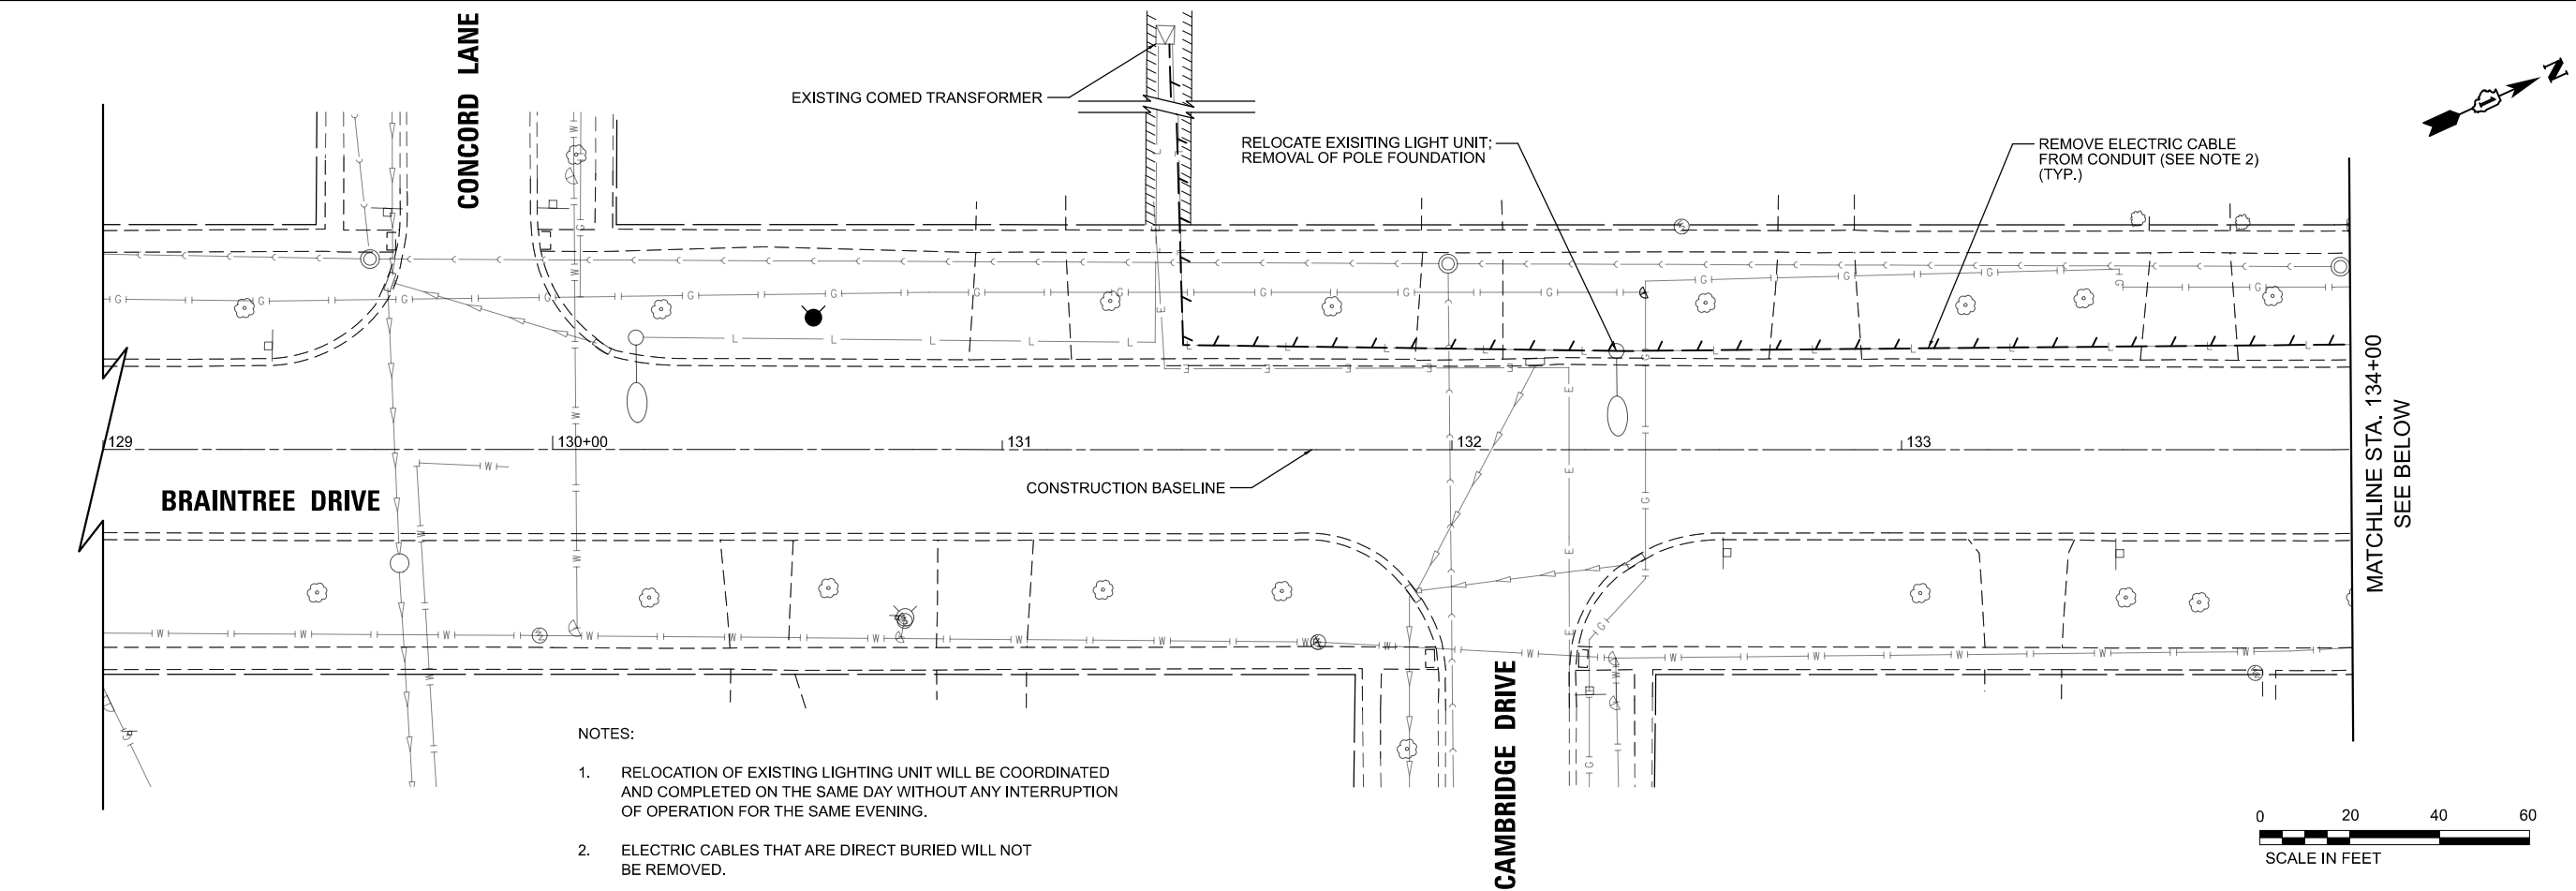


USER NAME = pk	DESIGNED - SJC	REVISED -
	DRAWN - SJC	REVISED -
	CHECKED - DNM	REVISED -
PLOT DATE = 12/15/2025	DATE - 12/12/2025	REVISED -

**STATE OF ILLINOIS
DEPARTMENT OF TRANSPORTATION**

**BRAINTREE DRIVE
LIGHTING REMOVAL PLAN**

SCALE: 1"=20' SHEET 3 OF 7 SHEETS STA. 129+00.00 TO STA. 139+00.00

MUN RTE.	SECTION	COUNTY	TOTAL SHEETS	SHEET NO.
4029	23-00146-00-PV	COOK	315	173
CONTRACT NO. 61M26				
ILLINOIS FED. AID PROJECT				

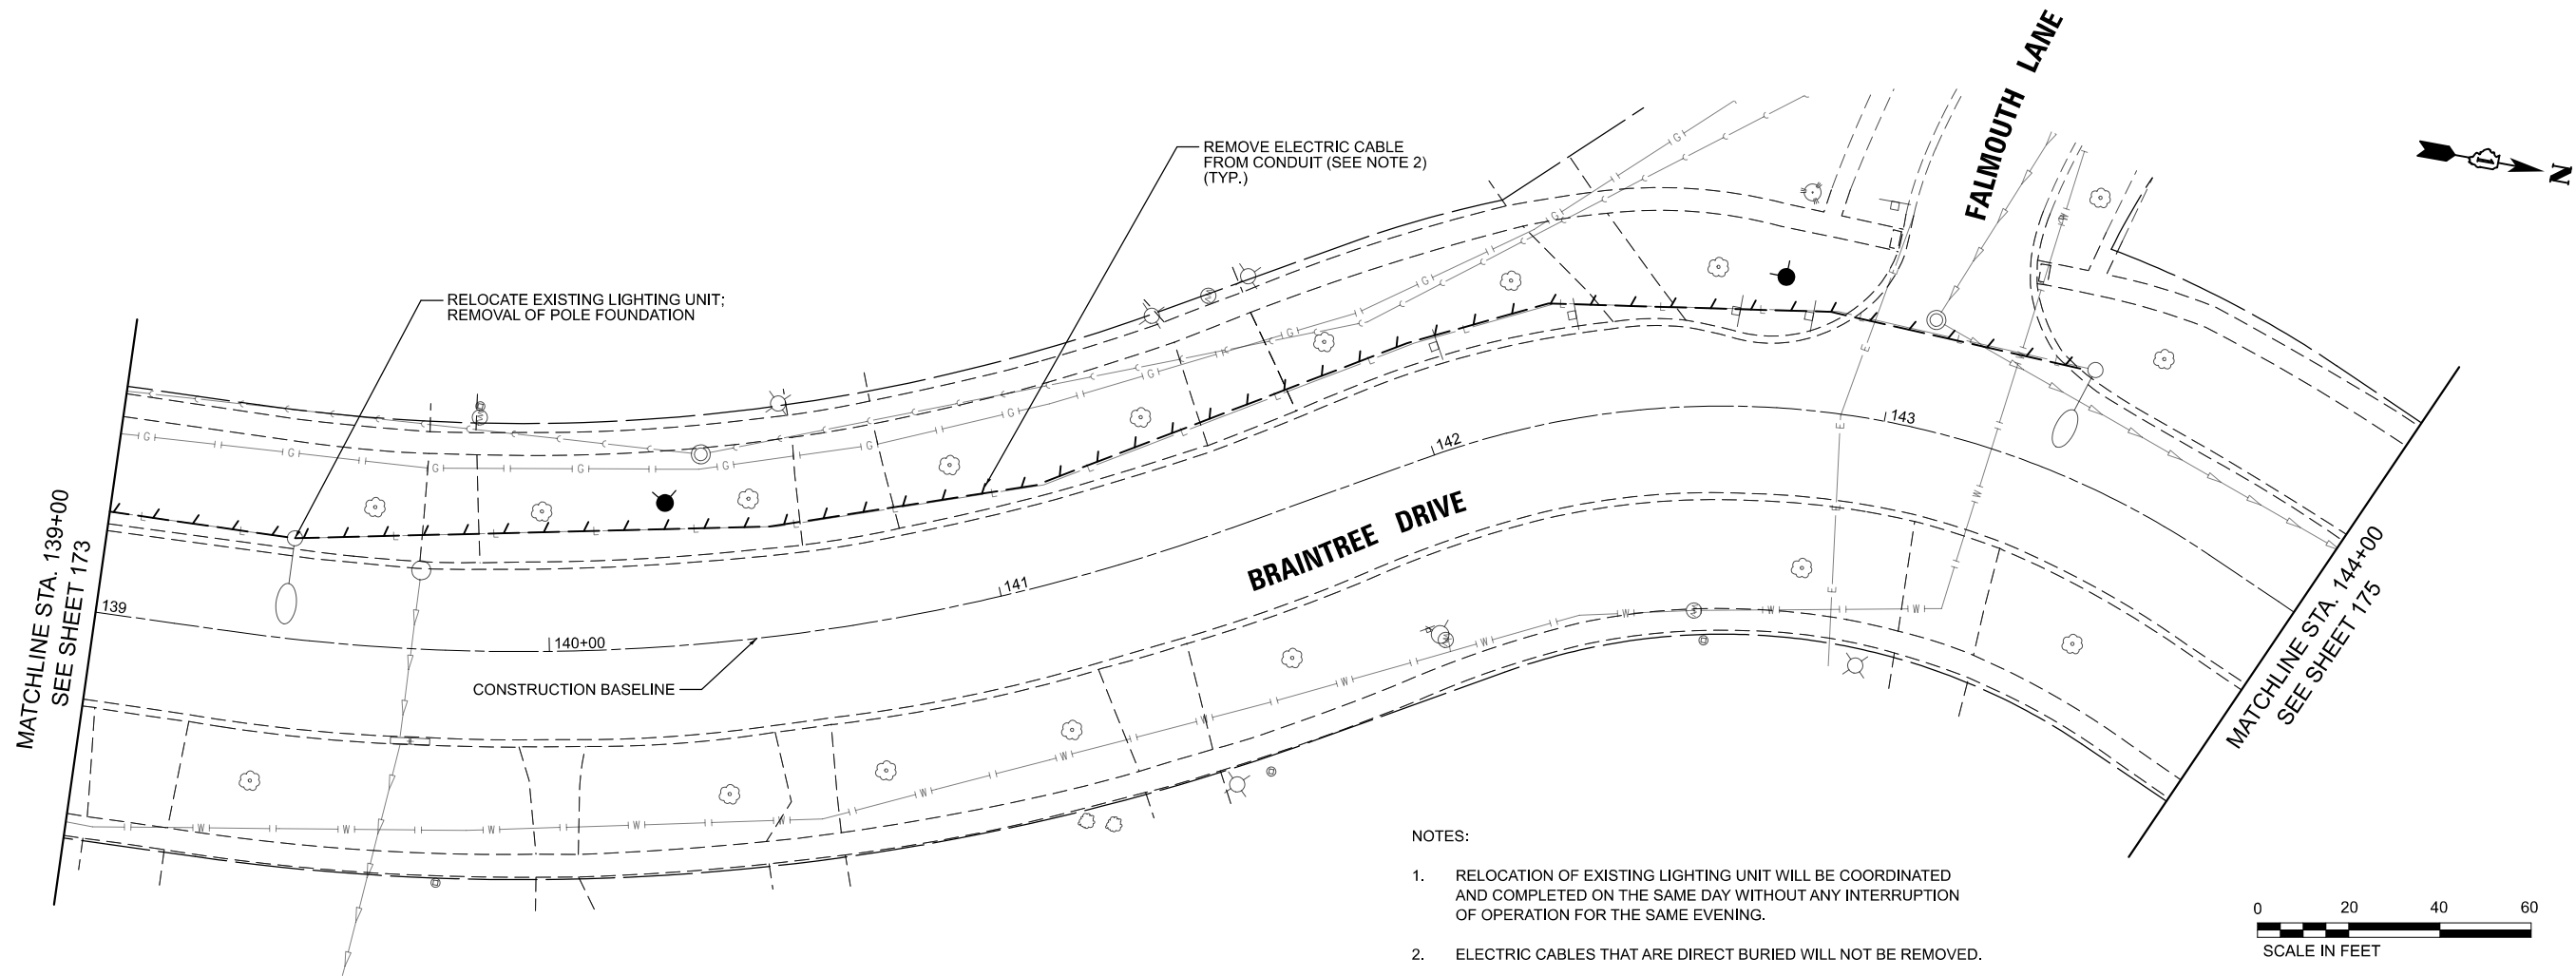

MODEL: Braintree - Plan 3 [Sheet]
FILE NAME: c:\bms\city\tech-pw\patro.kravets\0140571\3993-0201-sh14-lighting-02-07.dgn



USER NAME = pk	DESIGNED -	SJC	REVISED -
	DRAWN -	SJC	REVISED -
	CHECKED -	DNM	REVISED -
	DATE -	12/12/2025	REVISED -
PLOT DATE = 12/15/2025	DATE -	12/12/2025	REVISED -

STATE OF ILLINOIS
DEPARTMENT OF TRANSPORTATION

BRAINTREE DRIVE
LIGHTING REMOVAL PLAN

SCALE: 1"=20' SHEET 4 OF 7 SHEETS STA. 139+00.00 TO STA. 144+00.00

MUN RTE.	SECTION	COUNTY	TOTAL SHEETS	SHEET NO.
4029	23-00146-00-PV	COOK	315	174
CONTRACT NO. 61M26				
ILLINOIS FED. AID PROJECT				

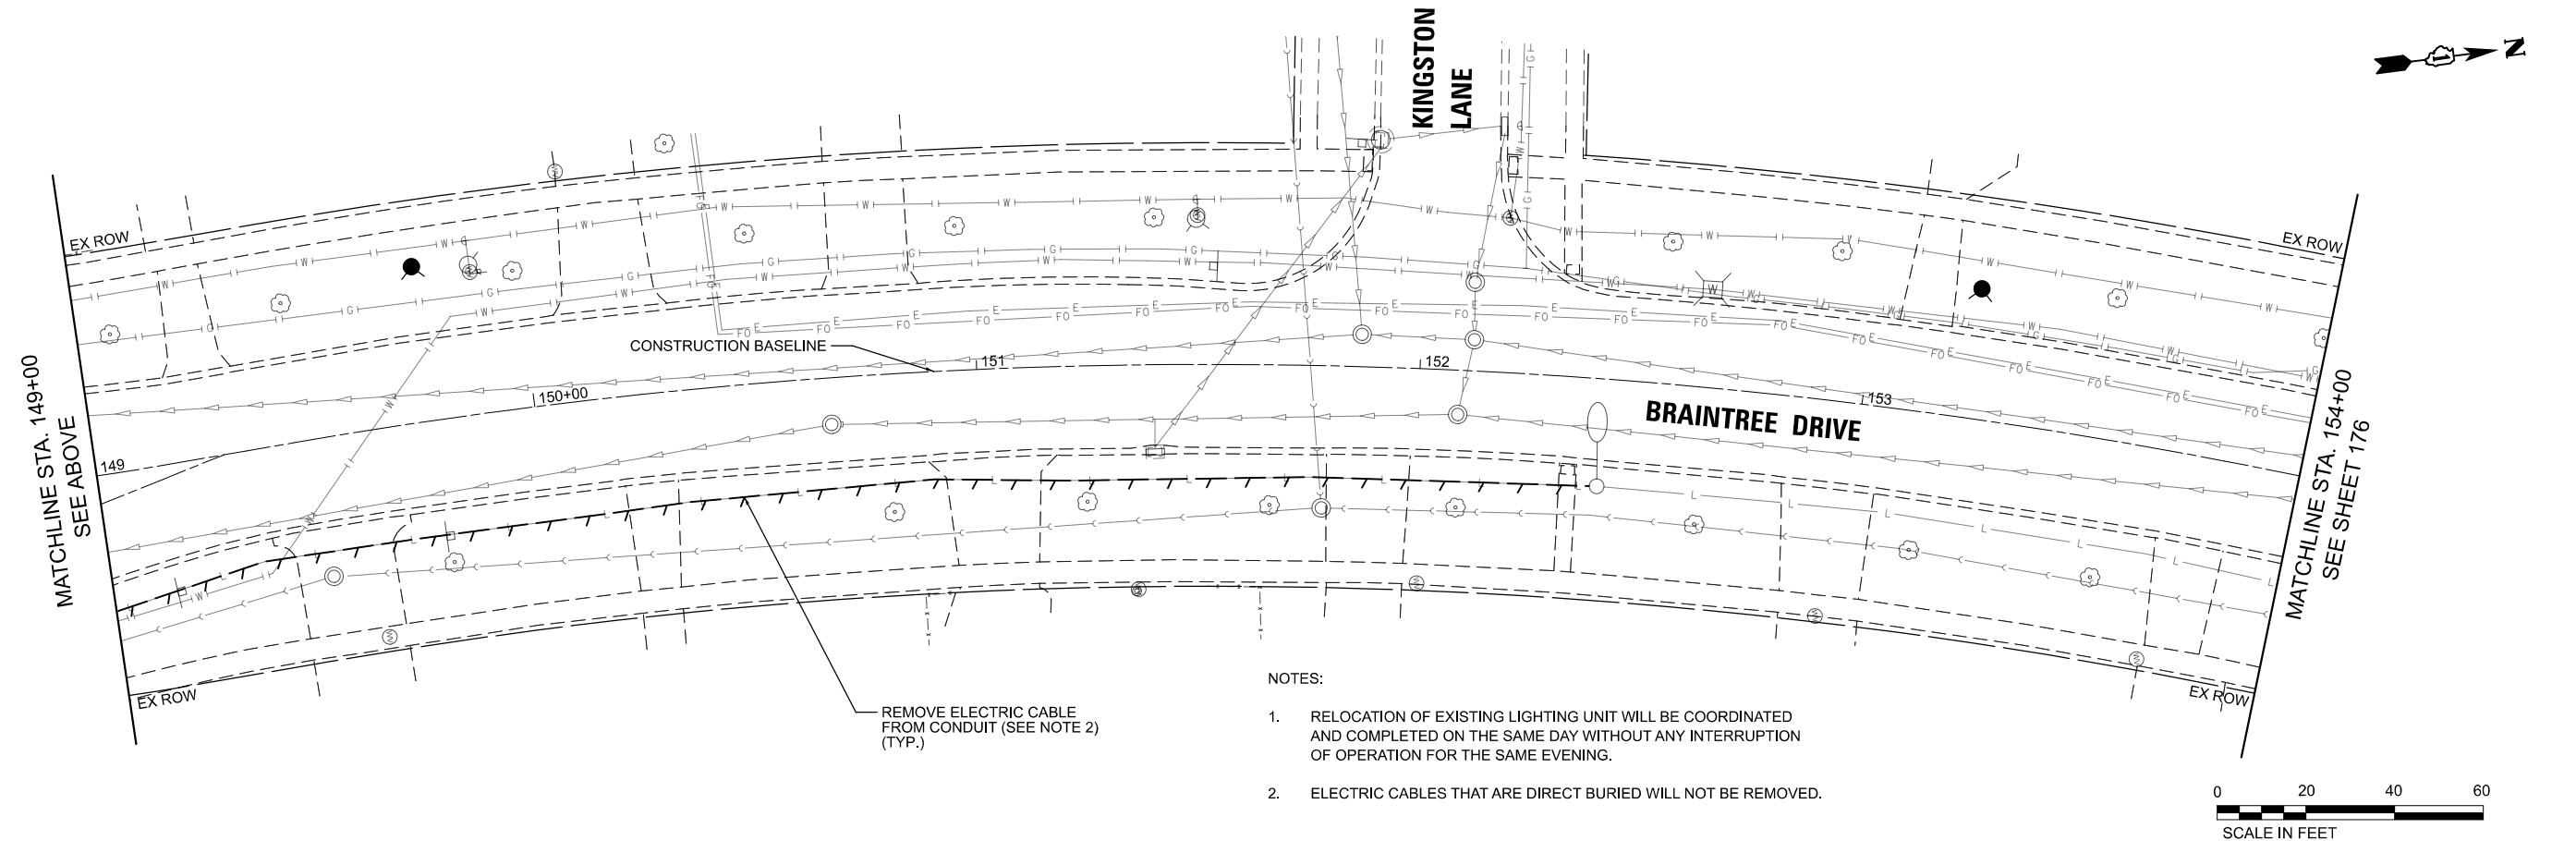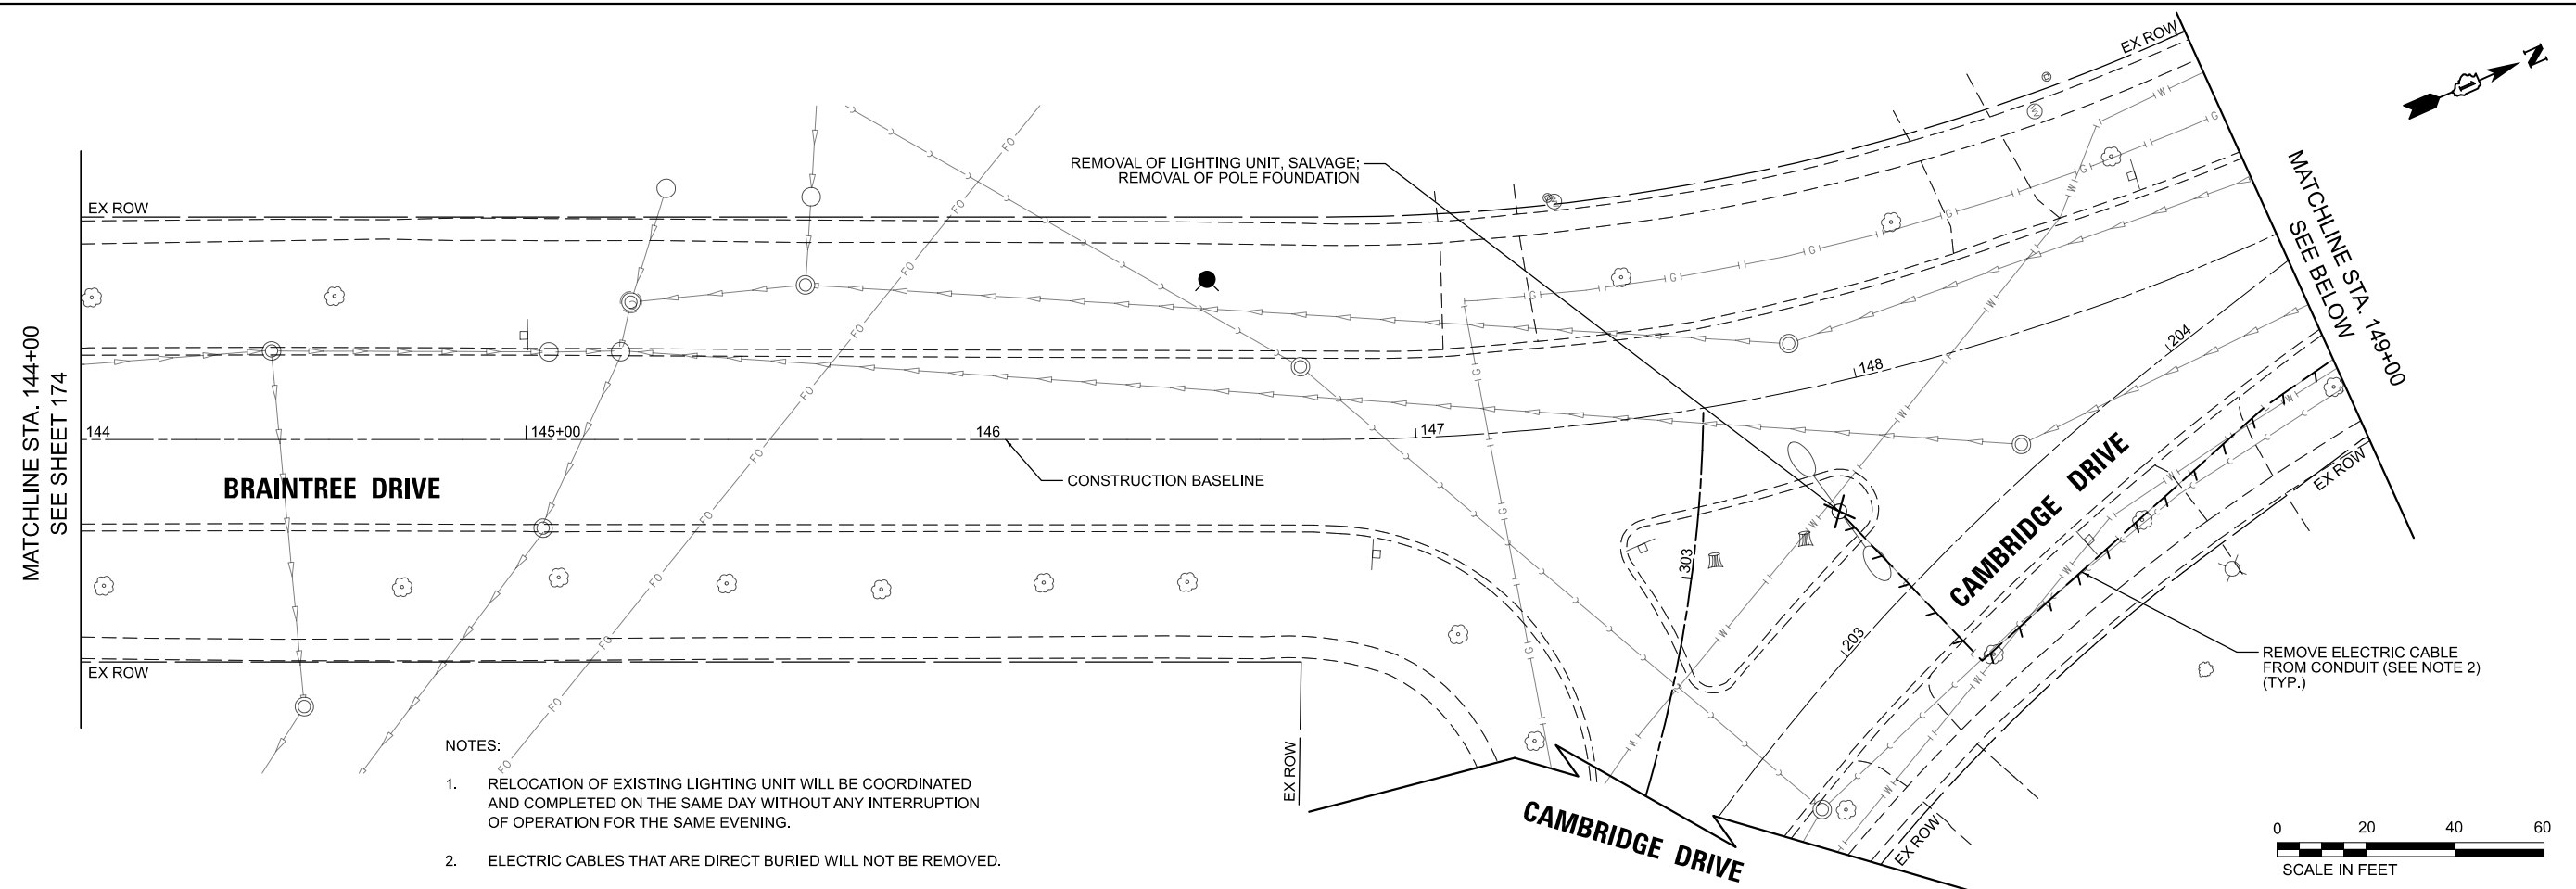

MODEL: Braintree - Plan 25 [Sheet]
FILE NAME: c:\bms\civiltech-pw\patro.kravets\01405713993-0201-shd-lighting-02-07.dgn



Two Pierce Place, Suite 1400
Itasca, Illinois 60143
Tel: 630.773.3900
Fax: 630.773.3975
www.civiltechinc.com

USER NAME = pk
PLOT DATE = 12/15/2025

DESIGNED -	SJC
DRAWN -	SJC
CHECKED -	DNM
DATE -	12/12/2025

REVISED -	
REVISED -	
REVISED -	
REVISED -	

STATE OF ILLINOIS
DEPARTMENT OF TRANSPORTATION

BRAINTREE DRIVE
LIGHTING REMOVAL PLAN

SCALE: 1"=20'

SHEET 6

OF 7

SHEETS

STA. 154+00.00

TO STA. 159+00.00

MUN
RTE.
4029


SECTION
23-00146-00-PV

COUNTY
COOK

TOTAL SHEETS 315	SHEET NO. 176
CONTRACT NO. 61M26	



ILLINOIS FED. AID PROJECT

MATCHLINE STA. 154+00
SEE SHEET 175

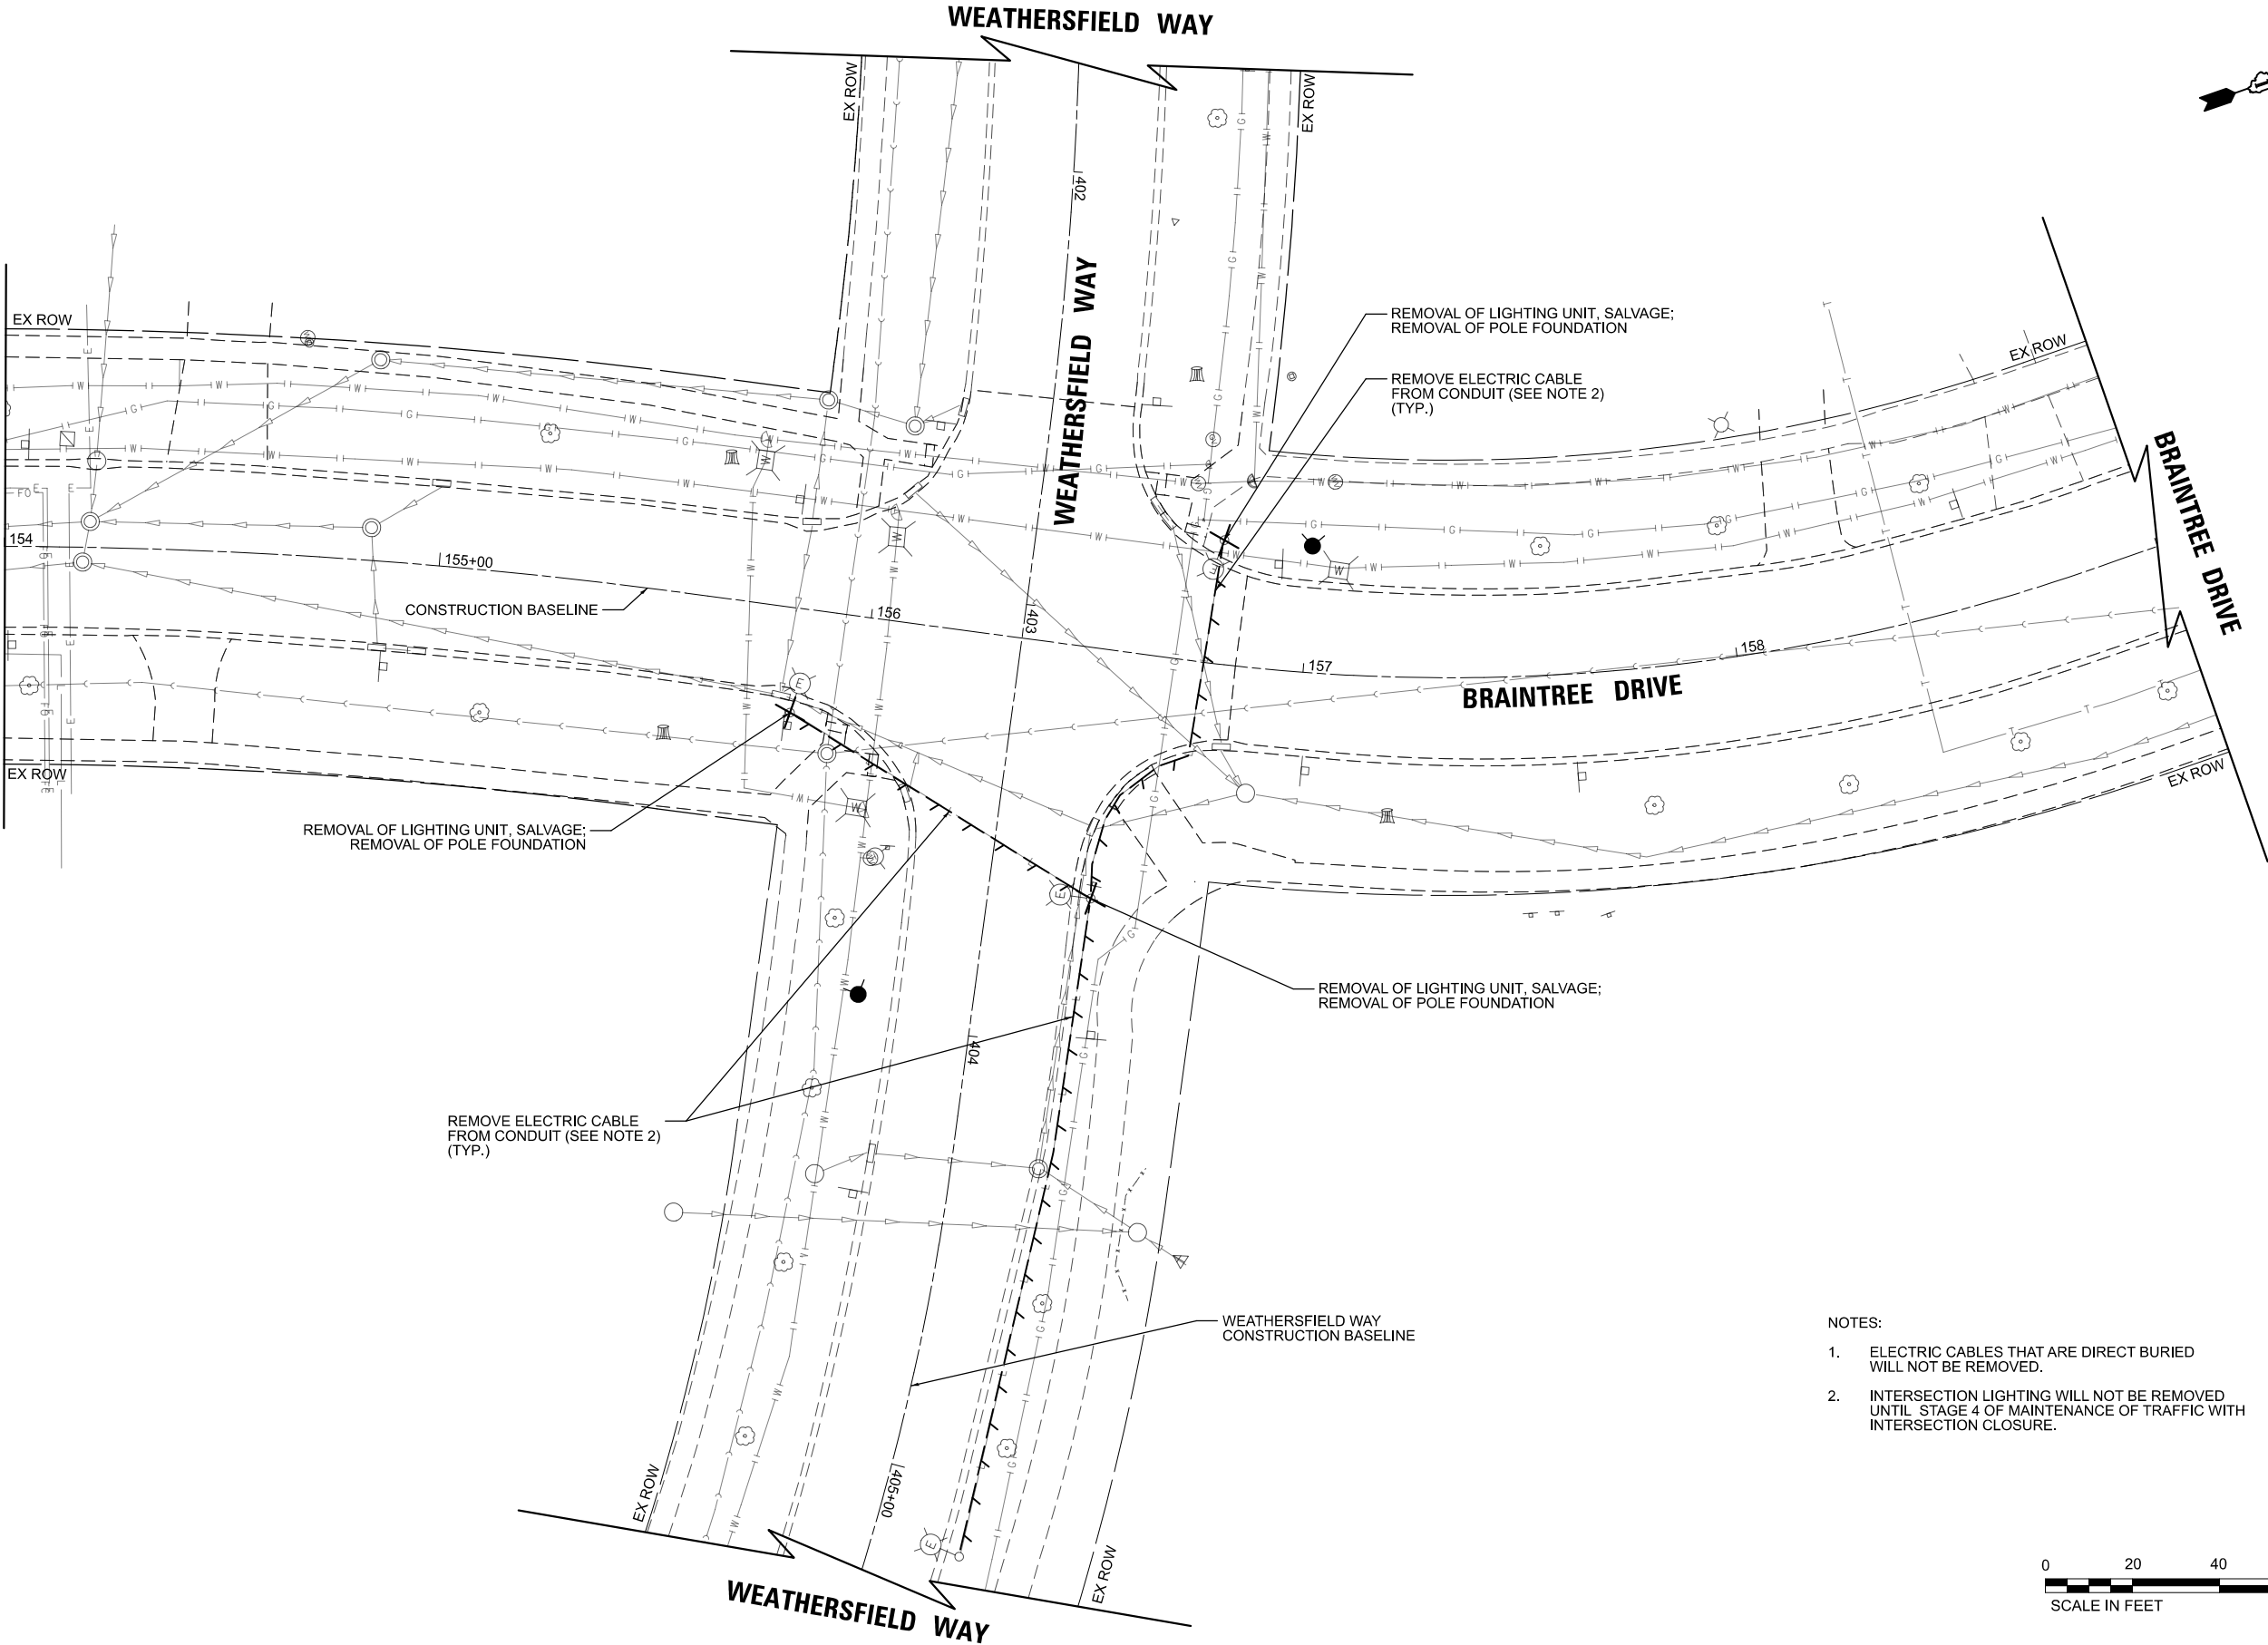

NOTES:

- ELECTRIC CABLES THAT ARE DIRECT BURIED WILL NOT BE REMOVED.
- INTERSECTION LIGHTING WILL NOT BE REMOVED UNTIL STAGE 4 OF MAINTENANCE OF TRAFFIC WITH INTERSECTION CLOSURE.

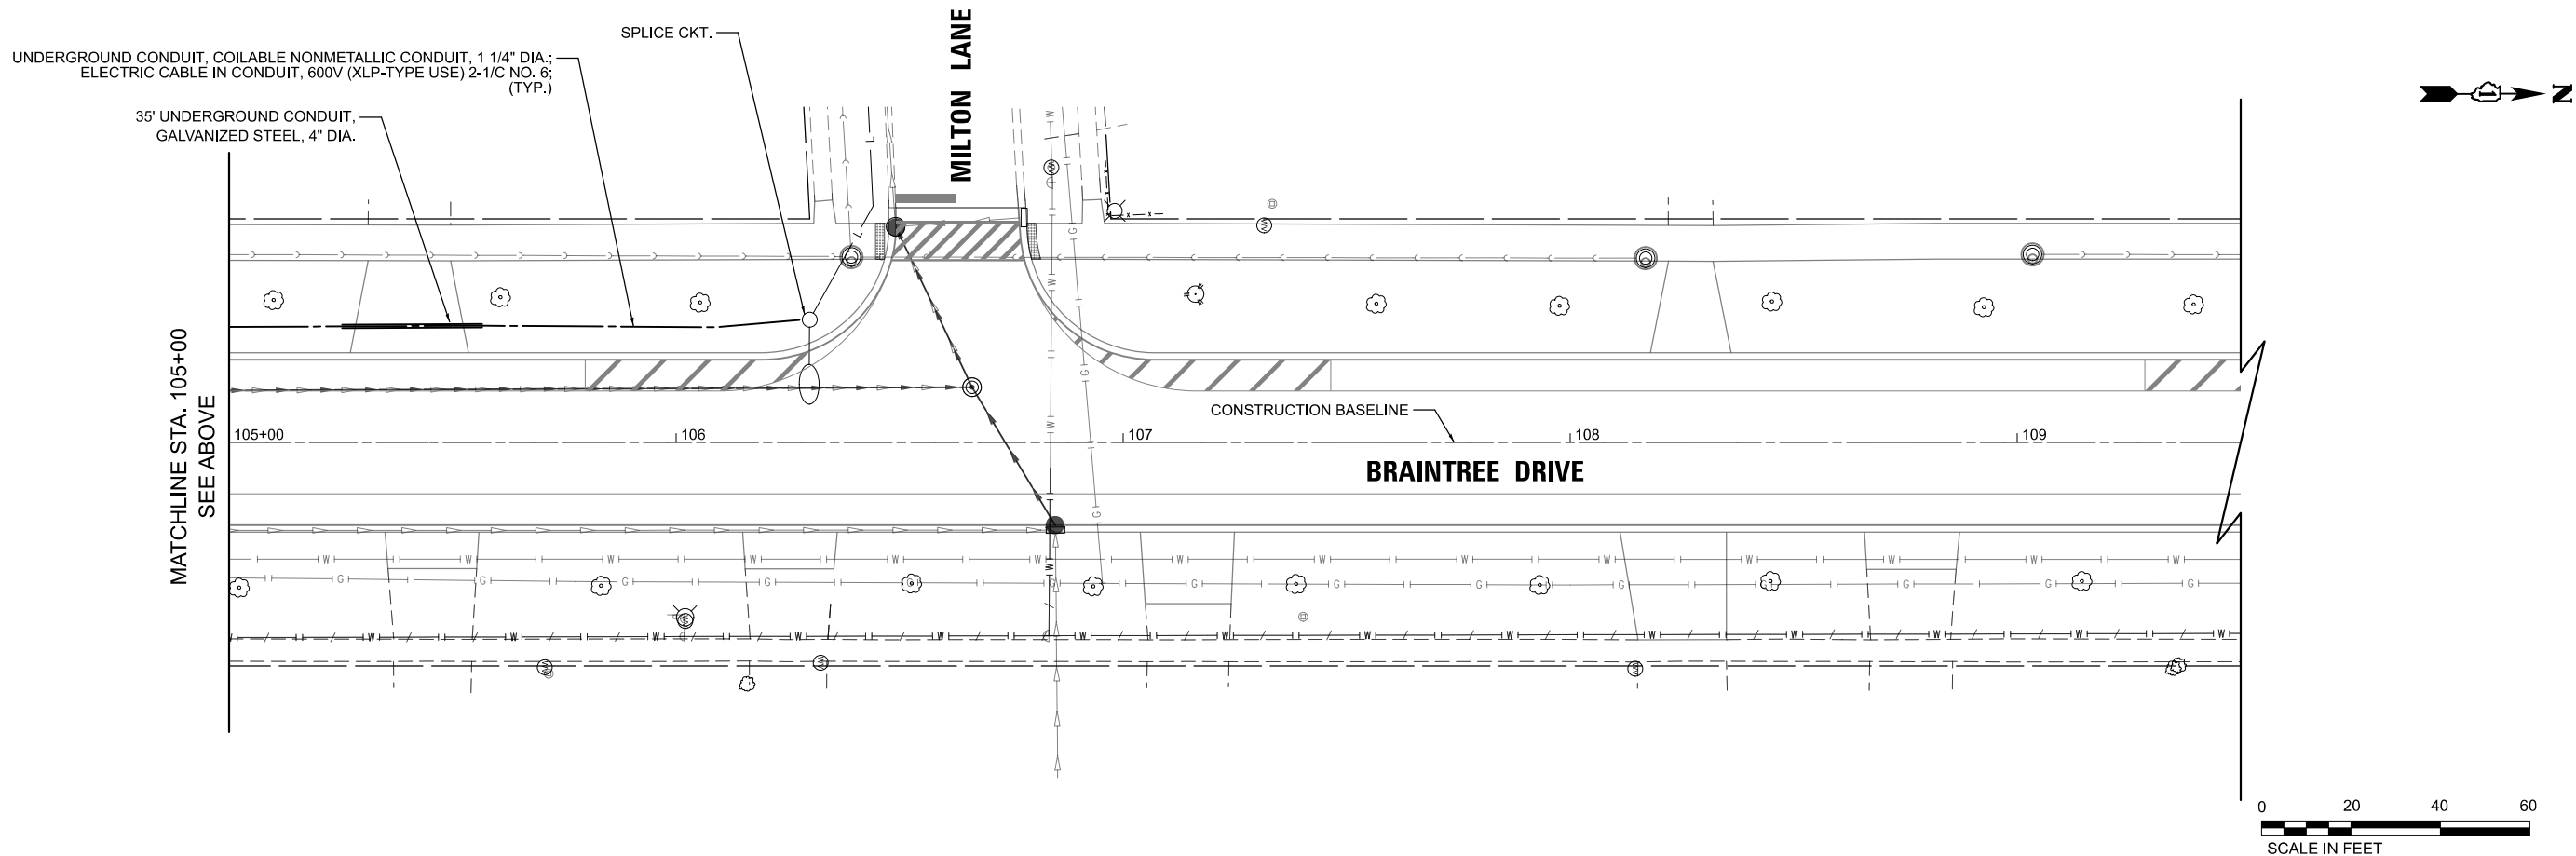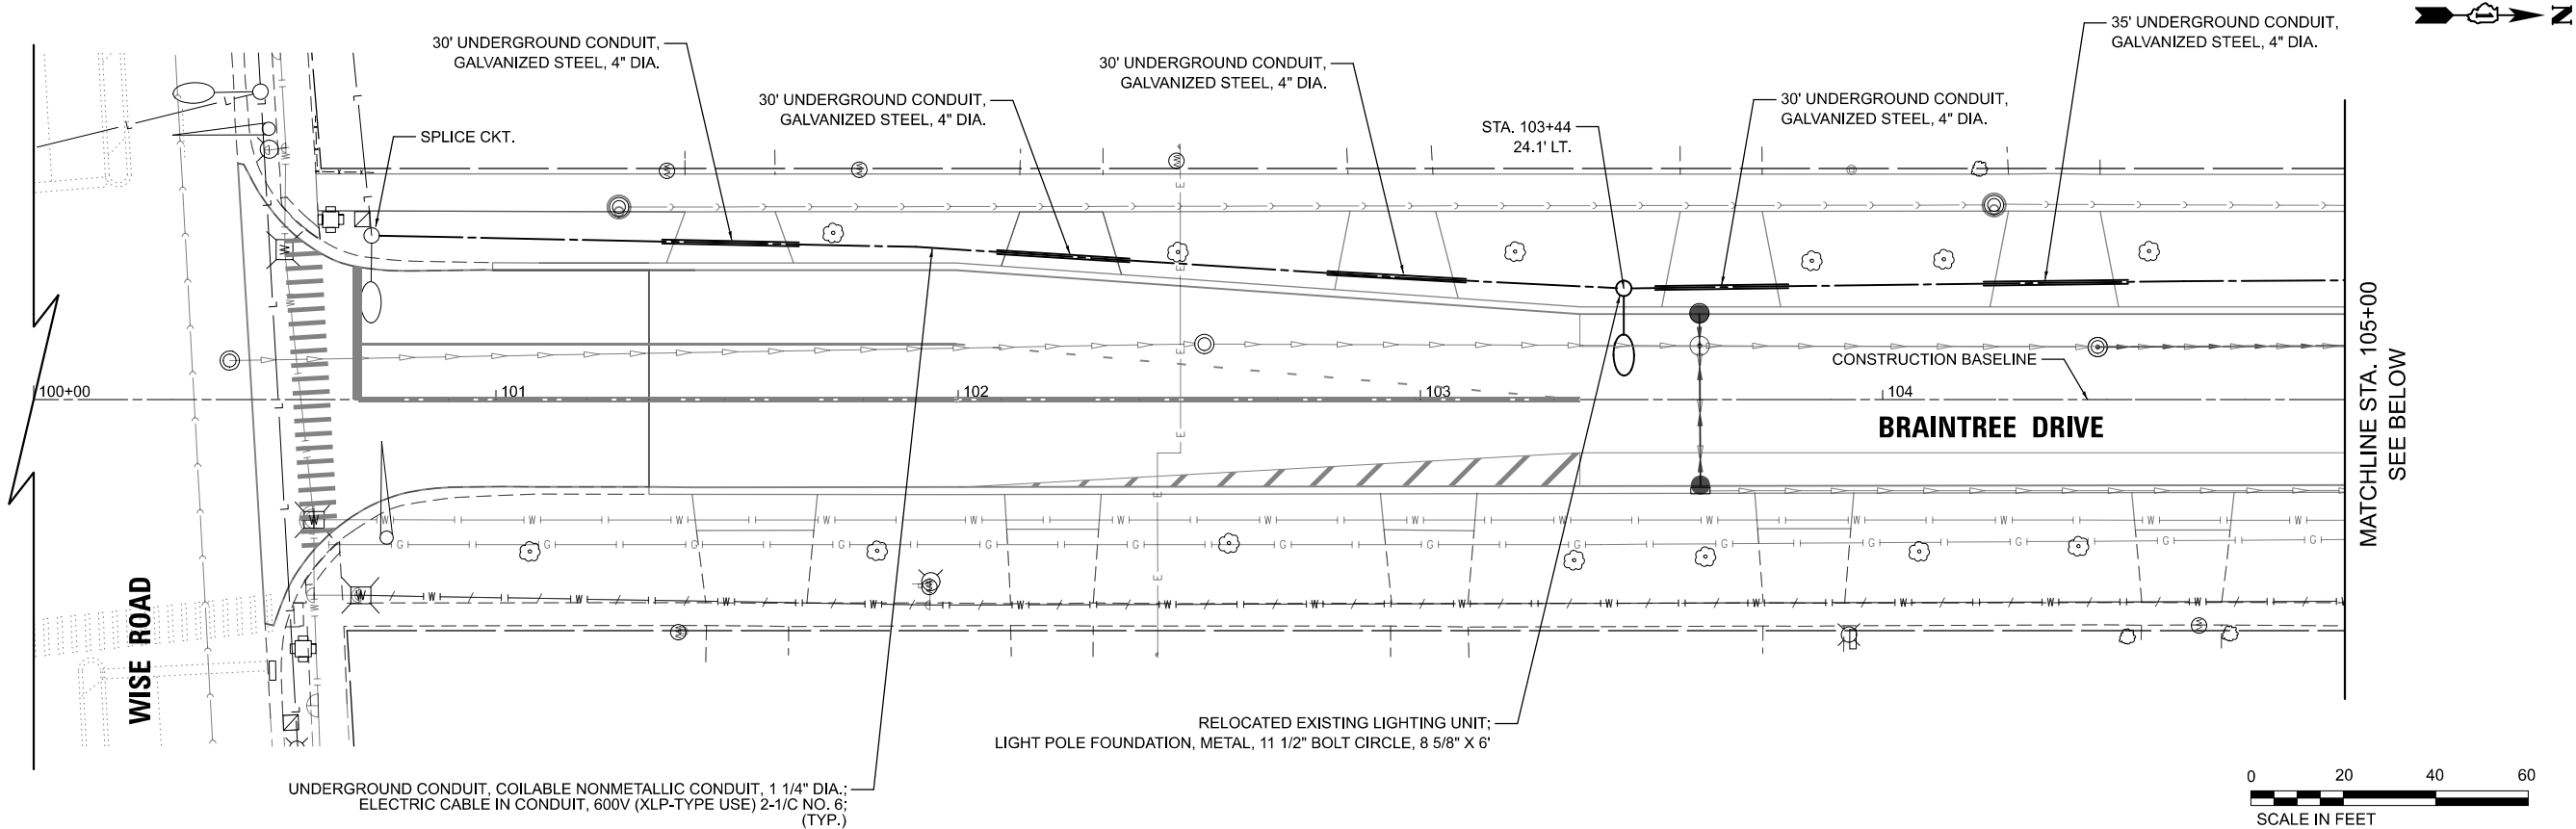

MODEL: Braintree - Plan (0-1 [Sheet])
FILE NAME: c:\bms\stl\litch-pv\patro.kravets\0140571\3393-0201-sh14-lighting 09-15.dgn

USER NAME = pk	DESIGNED - SJC	REVISED -
	DRAWN - SJC	REVISED -
	CHECKED - DNM	REVISED -
PLOT DATE = 12/11/2025	DATE - 12/12/2025	REVISED -


STATE OF ILLINOIS
DEPARTMENT OF TRANSPORTATION

BRAINTREE DRIVE
LIGHTING PROPOSED PLAN

SCALE: 1"=20' SHEET 1 OF 8 SHEETS STA. 100+00.00 TO STA. 105+00.00

MUN RTE.	SECTION	COUNTY	TOTAL SHEETS	SHEET NO.
4029	23-00146-00-PV	COOK	315	178
CONTRACT NO. 61M26				
ILLINOIS FED. AID PROJECT				

MODEL: Braintree - Plan (A-3) [Sheet]
FILE NAME: c:\bms\stl\tech-pw\patro.kravets\dd140571\3993-0201-shd-lighting 09-15.dgn

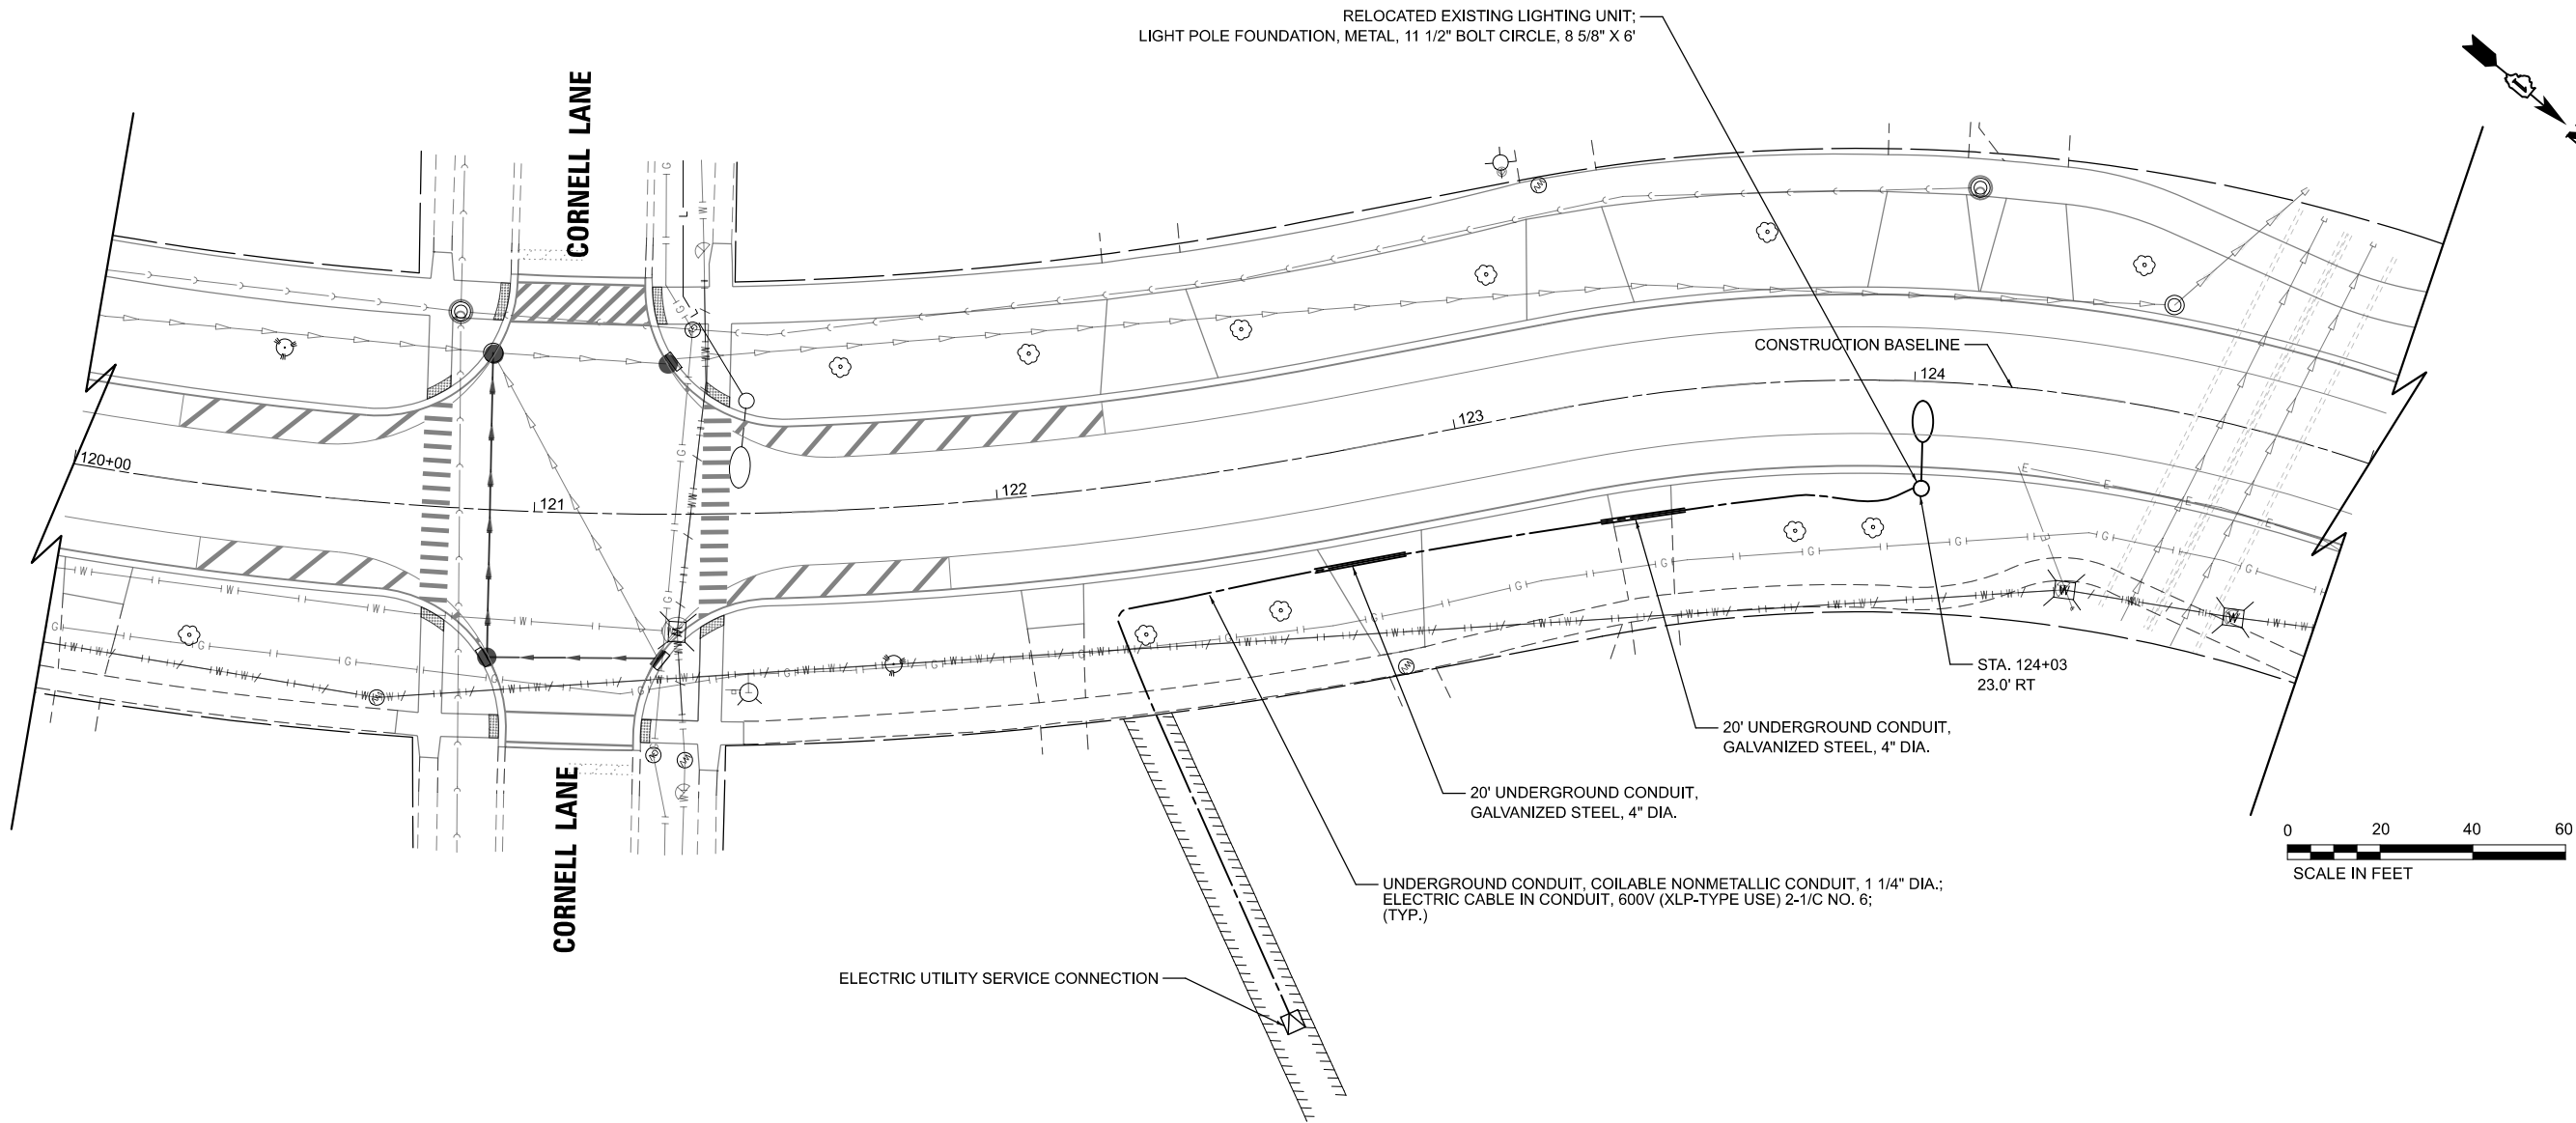



USER NAME = pk	DESIGNED -	SJC	REVISED -	
	DRAWN -	SJC	REVISED -	
	CHECKED -	DNM	REVISED -	
	DATE -	12/12/2025	REVISED -	
PLOT DATE = 12/15/2025	DATE -	12/12/2025	REVISED -	

STATE OF ILLINOIS
DEPARTMENT OF TRANSPORTATION

BRAINTREE DRIVE
LIGHTING PROPOSED PLAN

SCALE: 1"=20' SHEET 2 OF 8 SHEETS STA. 120+00.00 TO STA. 125+00.00

MUN RTE.	SECTION	COUNTY	TOTAL SHEETS	SHEET NO.
4029	23-00146-00-PV	COOK	315	179
CONTRACT NO. 61M26				
ILLINOIS FED. AID PROJECT				

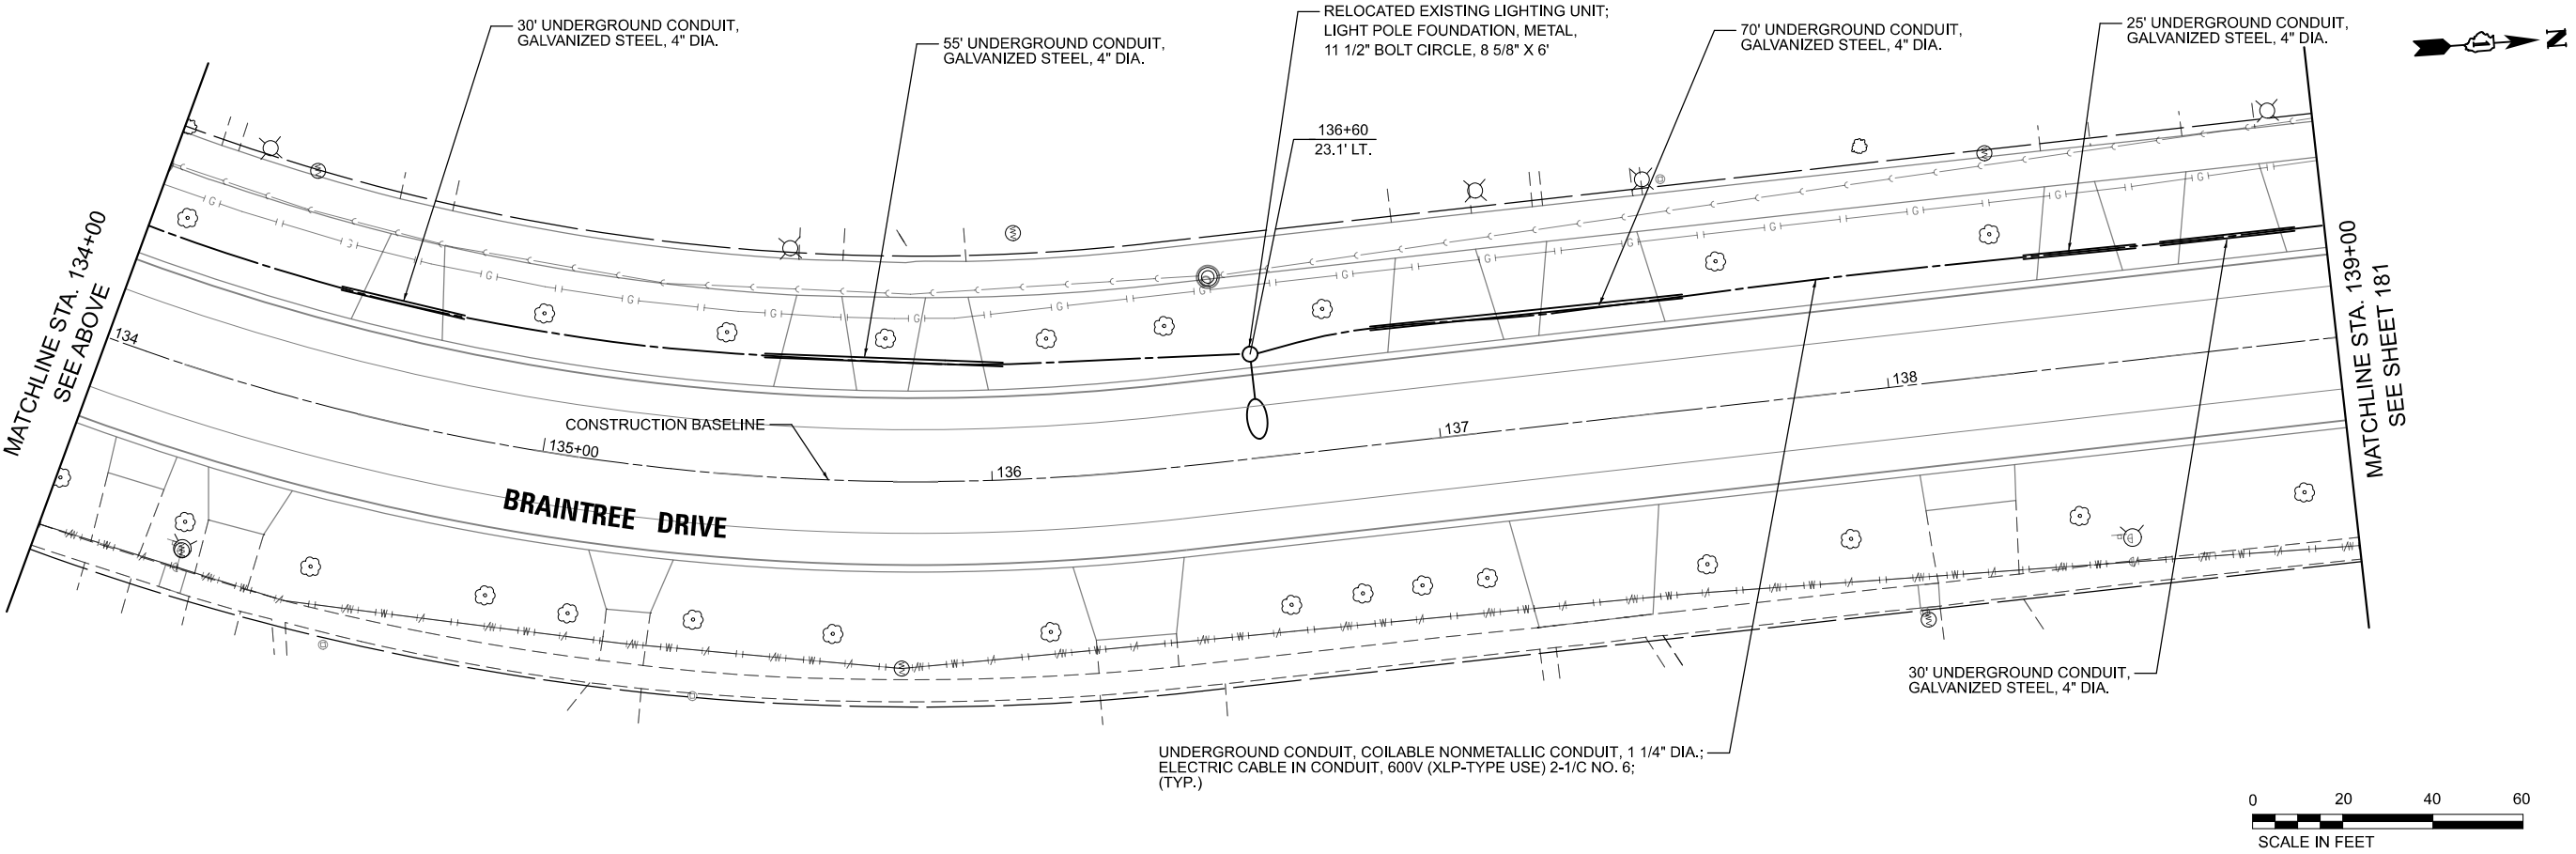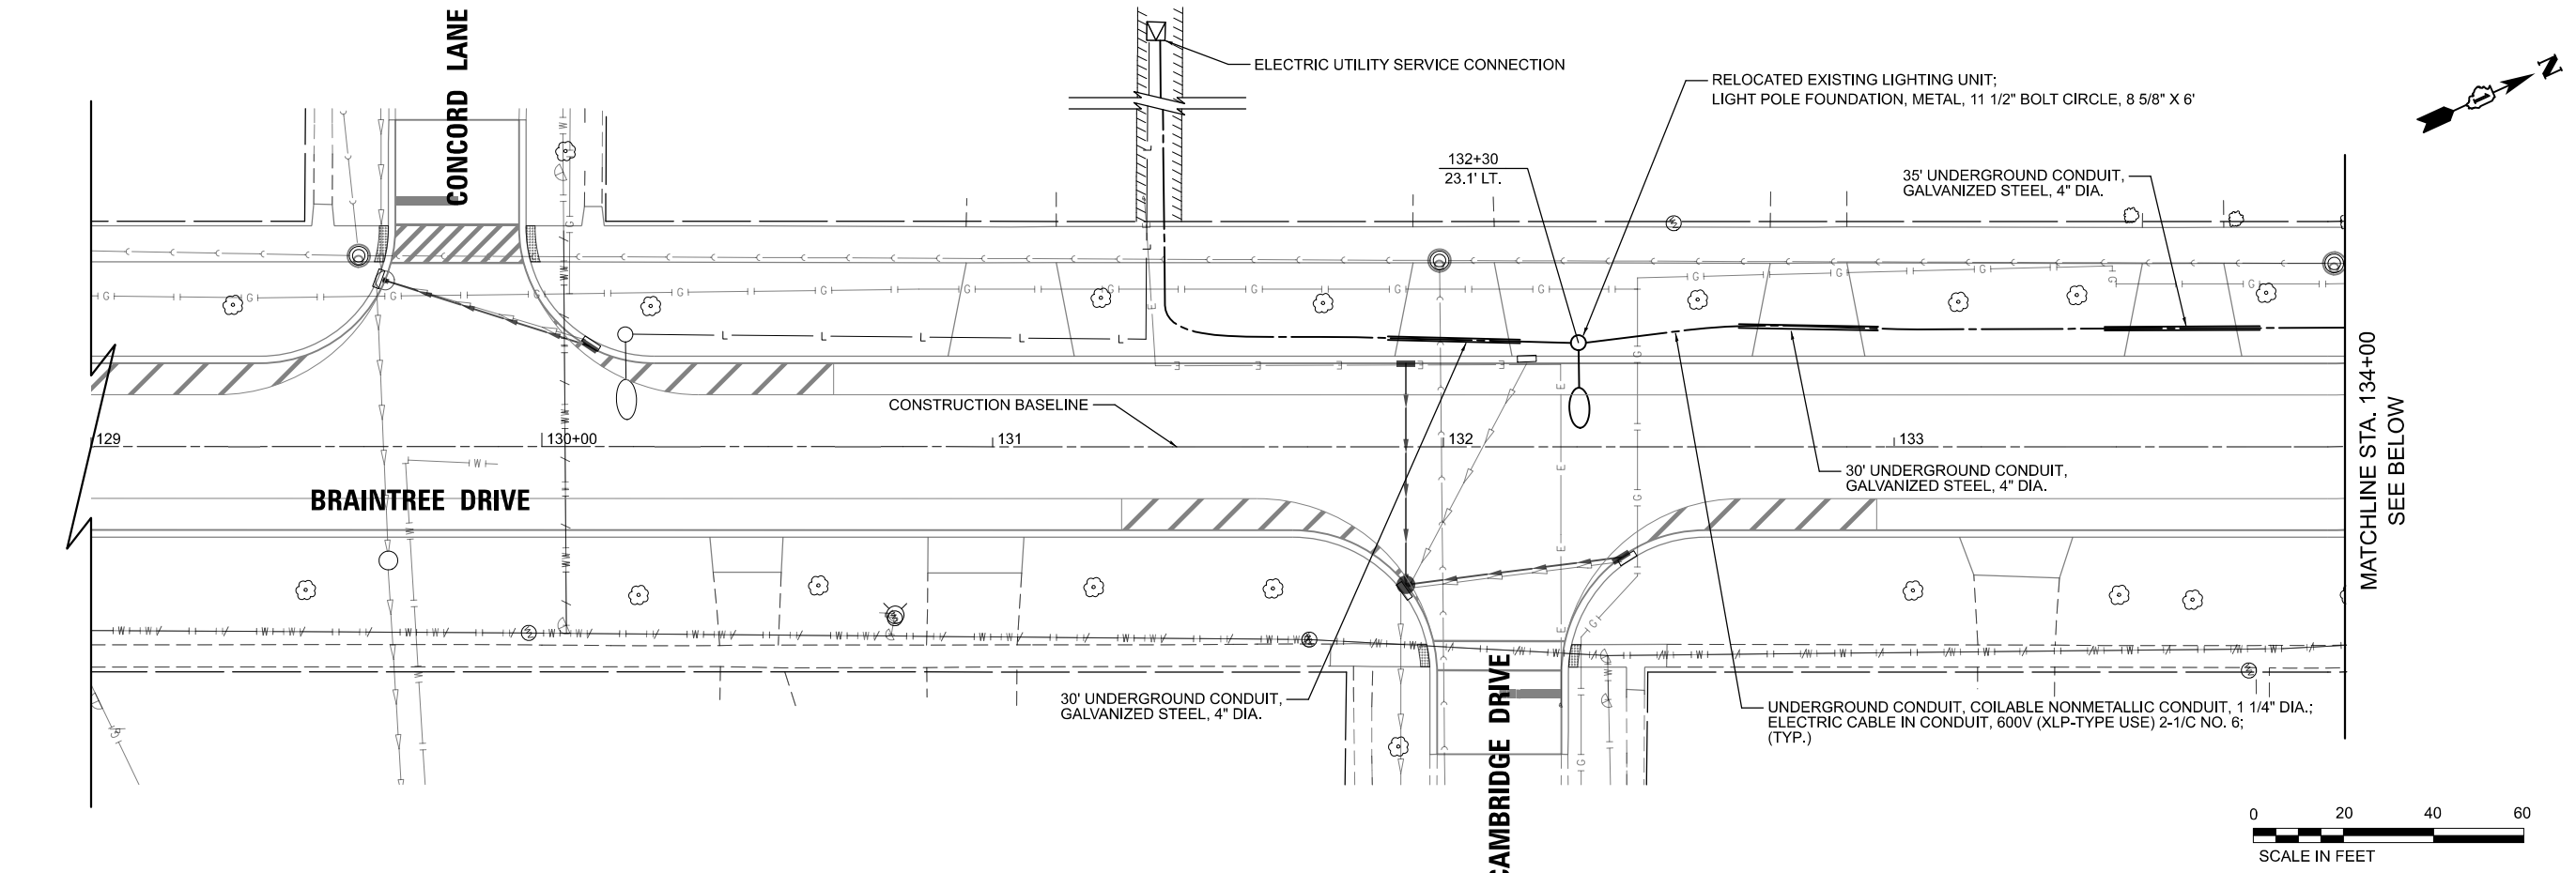

MODEL: Braintree - Plan 1 [Sheet]
FILE NAME: c:\bms\sketch-pw\patro.kravets\014057133993-0201-shd-lighting 09-15.dgn


USER NAME = pk	DESIGNED -	SJC	REVISED -	
	DRAWN -	SJC	REVISED -	
	CHECKED -	DNM	REVISED -	
	DATE -	12/12/2025	REVISED -	
PLOT DATE = 12/15/2025				

STATE OF ILLINOIS
DEPARTMENT OF TRANSPORTATION

BRAINTREE DRIVE
LIGHTING PROPOSED PLAN

SCALE: 1"=20' SHEET 3 OF 8 SHEETS STA. 129+00.00 TO STA. 139+00.00

MUN RTE.	SECTION	COUNTY	TOTAL SHEETS	SHEET NO.
4029	23-00146-00-PV	COOK	315	180
CONTRACT NO. 61M26				
ILLINOIS FED. AID PROJECT				

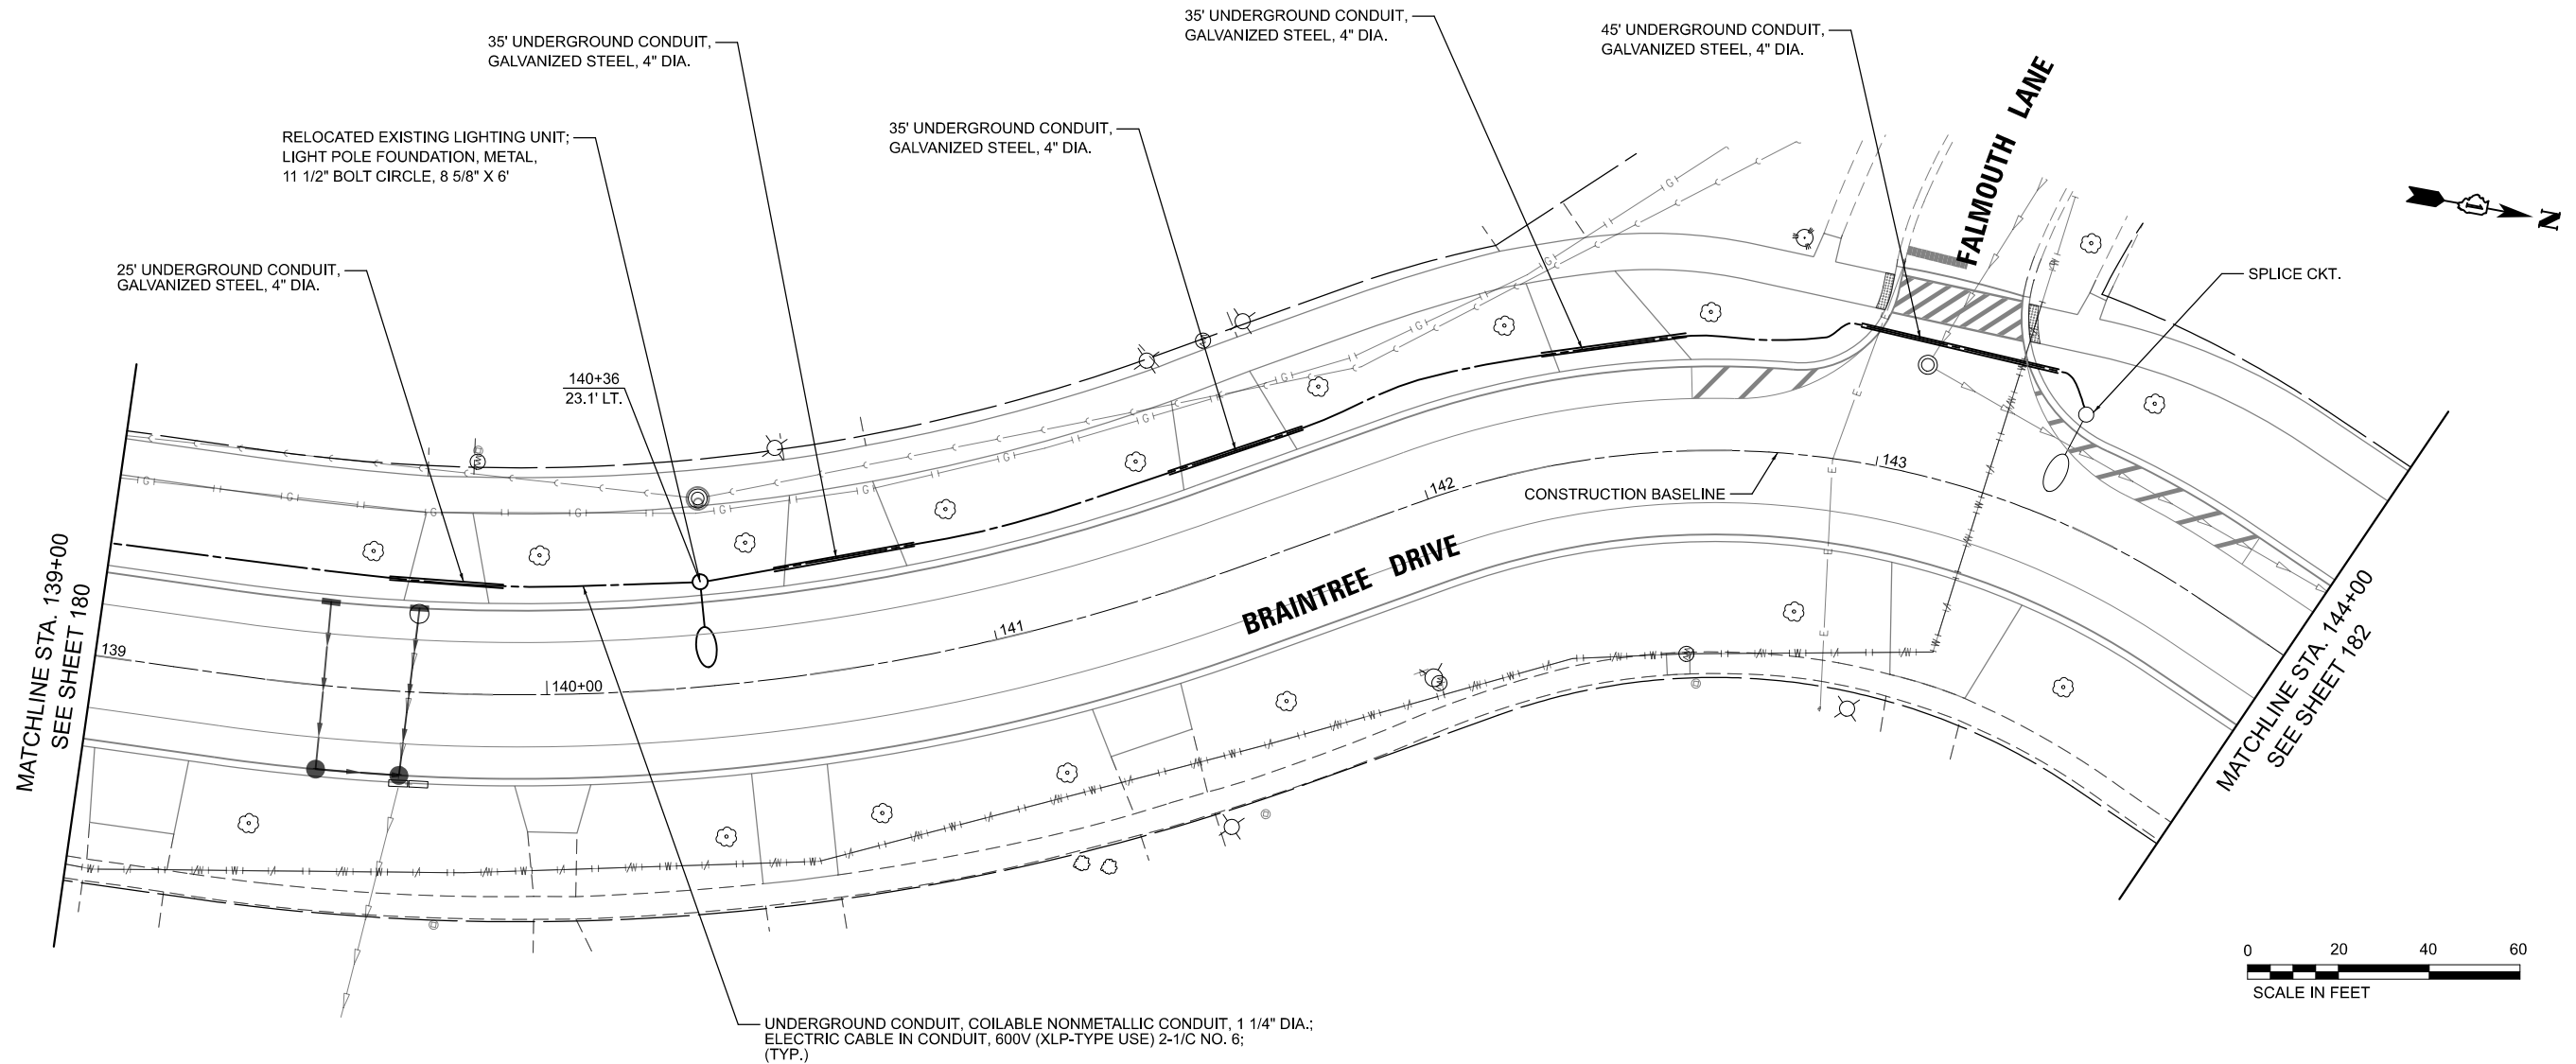

MODEL: Braintree - Plan 3 [Sheet]
FILE NAME: c:\bms\city\litch-pw\patro.kravets\0140571\3993-0201-shd-lighting 09-15.dgn

	USER NAME	= pk	DESIGNED	-	SJC	REVISED	-
	DRAWN	-	SJC	REVISED	-		
	CHECKED	-	DNM	REVISED	-		
	PLOT DATE	= 12/15/2025	DATE	-	12/12/2025	REVISED	-

STATE OF ILLINOIS
DEPARTMENT OF TRANSPORTATION

BRAINTREE DRIVE
LIGHTING PROPOSED PLAN

SCALE: 1"=20'
SHEET 4 OF 8 SHEETS
STA. 139+00.00 TO STA. 144+00.00

MUN. RTE.	SECTION	COUNTY	TOTAL SHEETS	SHEET NO.
4029	23-00146-00-PV	COOK	315	181
CONTRACT NO. 61M26				
ILLINOIS FED. AID PROJECT				

MODEL: Braintree - Plan 25 [Sheet]
FILE NAME: c:\bms\civiltech\pw\patro.kravets\01405713993-0201-shd-lighting 09-15.dgn



Two Pierce Place, Suite 1400
Itasca, Illinois 60143
Tel: 630.773.3900
Fax: 630.773.3975
www.civiltechinc.com

USER NAME = pk
PLOT DATE = 12/15/2025


DESIGNED -	SJC	REVISED -	
DRAWN -	SJC	REVISED -	
CHECKED -	DNM	REVISED -	
DATE -	12/12/2025	REVISED -	

STATE OF ILLINOIS
DEPARTMENT OF TRANSPORTATION

BRAINTREE DRIVE
LIGHTING PROPOSED PLAN

SCALE: 1"=20' SHEET 6 OF 8 SHEETS STA. 154+00.00 TO STA. 159+00.00


MUN RTE.	SECTION	COUNTY	TOTAL SHEETS	SHEET NO.
4029	23-00146-00-PV	COOK	315	183
CONTRACT NO. 61M26				
ILLINOIS FED. AID PROJECT				

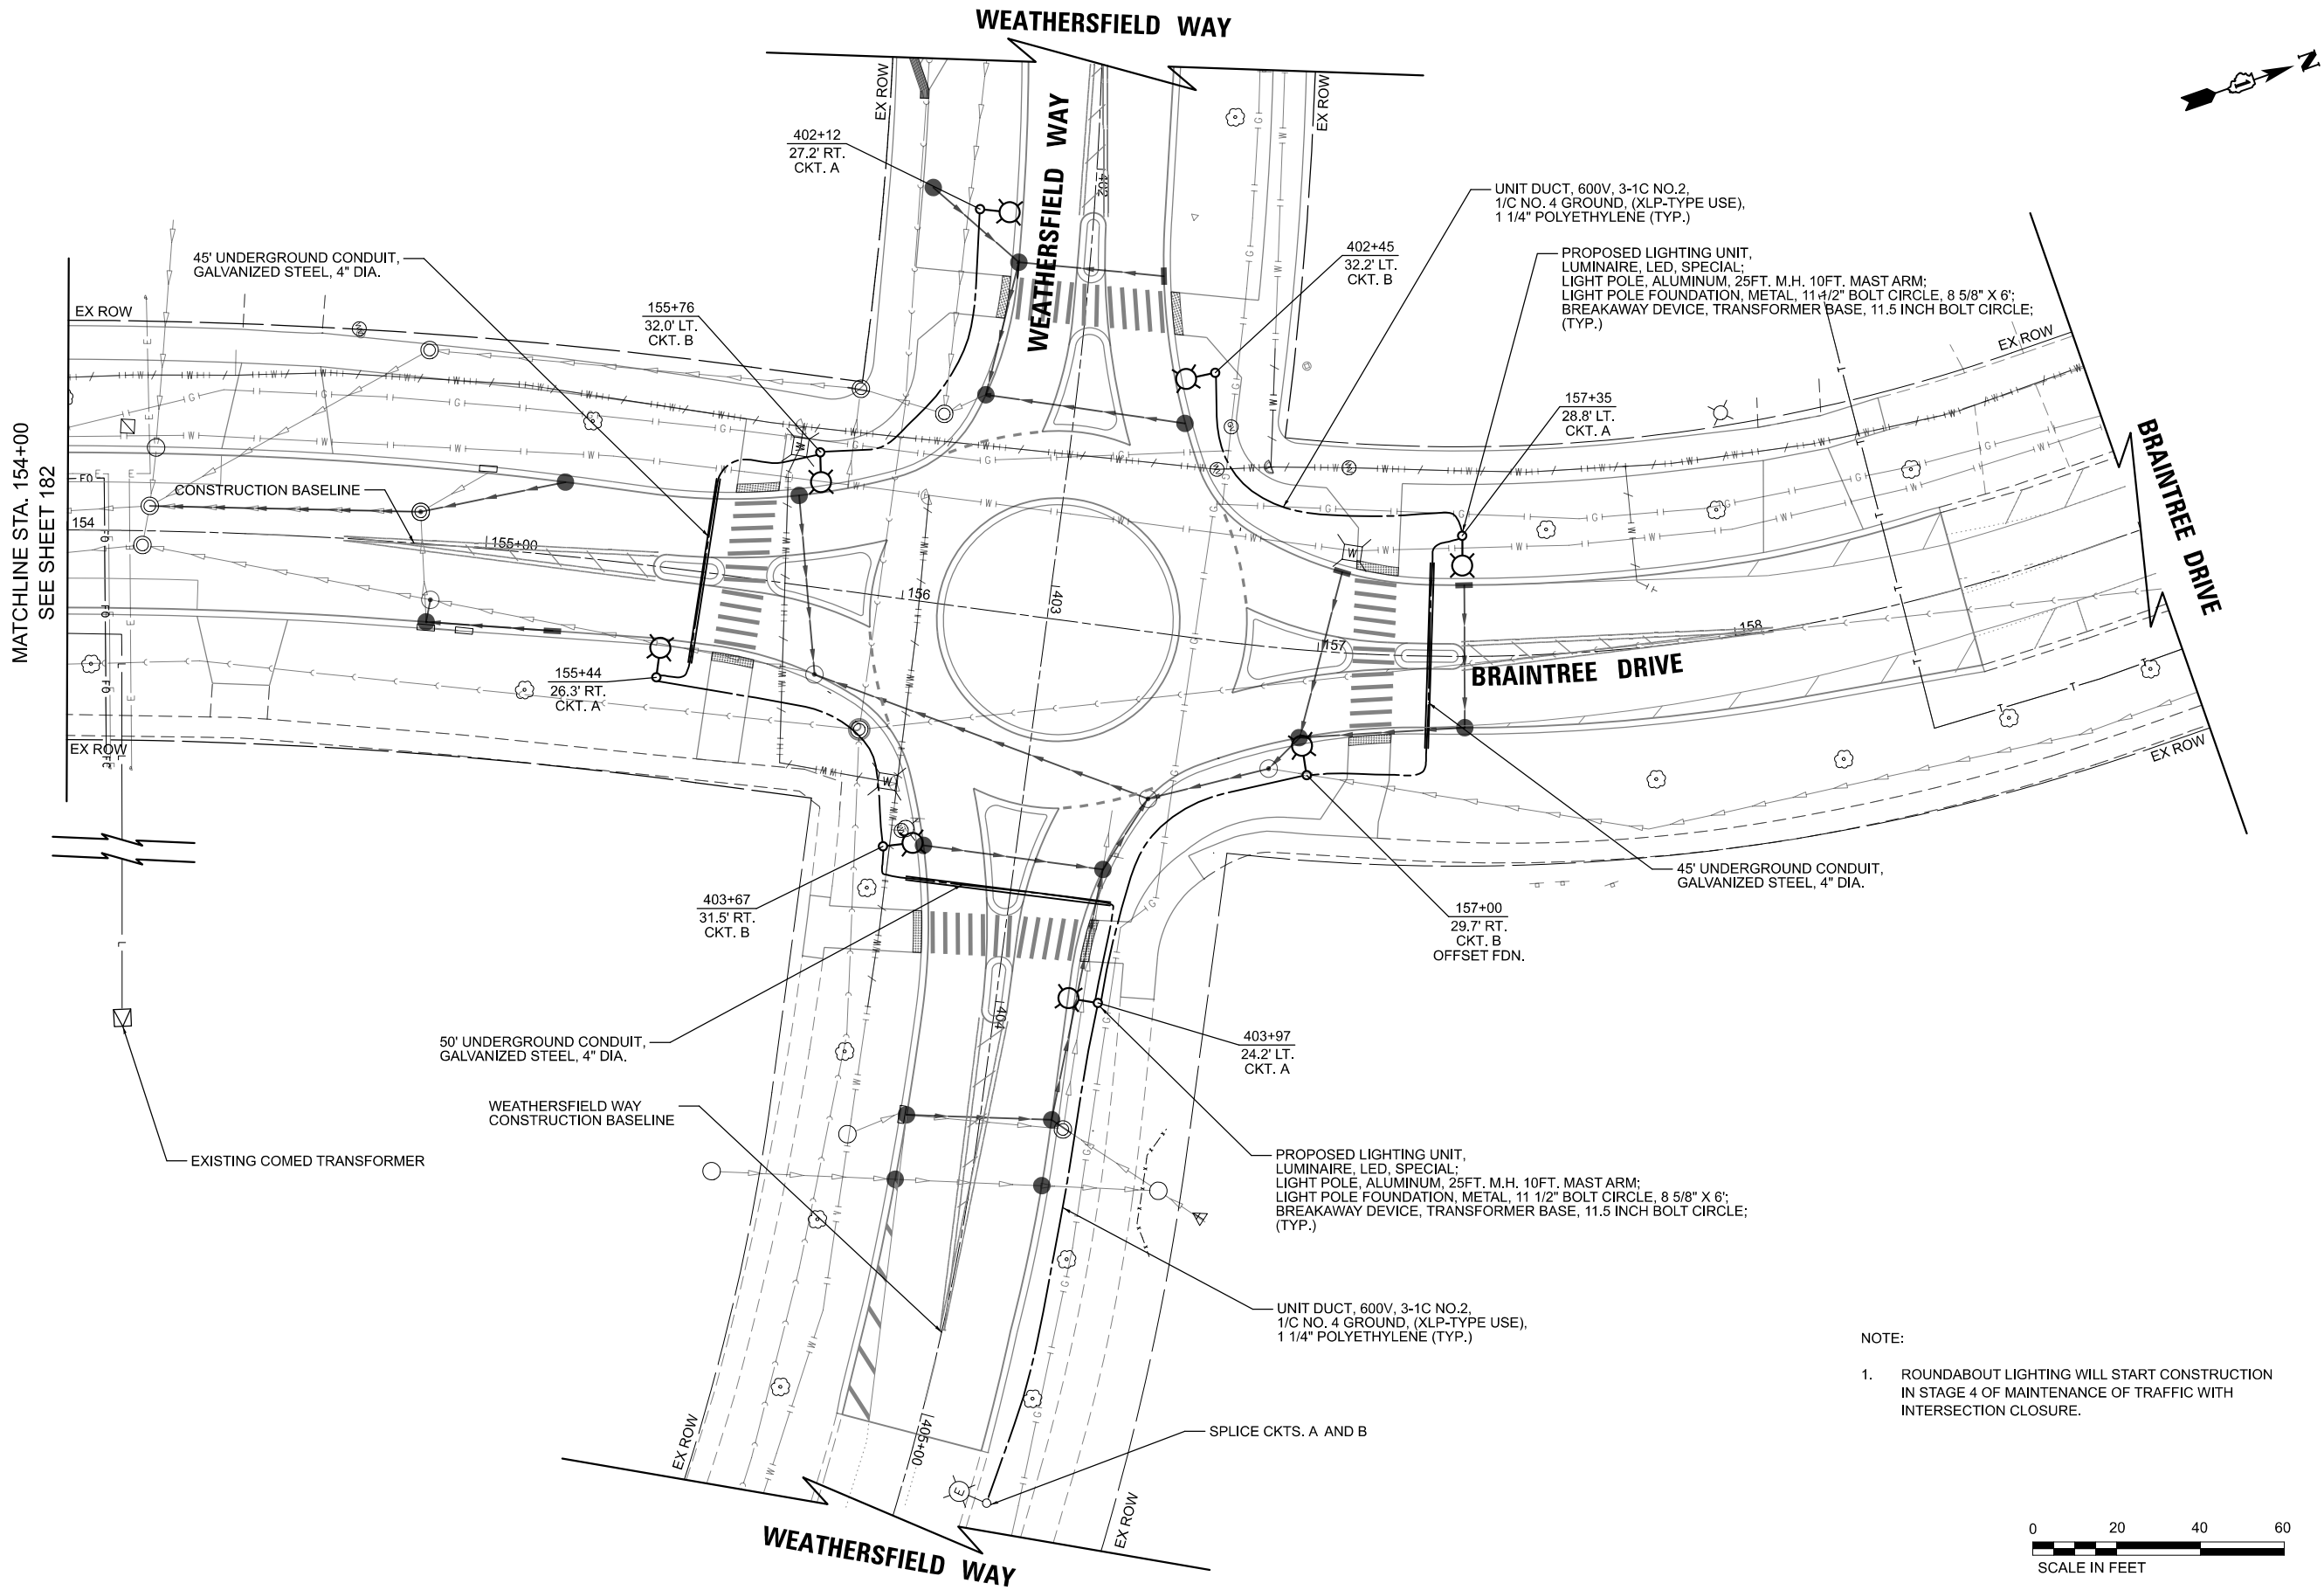

- NOTE:
1. ROUNDABOUT LIGHTING WILL START CONSTRUCTION IN STAGE 4 OF MAINTENANCE OF TRAFFIC WITH INTERSECTION CLOSURE.



MODEL: Cambridge - Plan 1 [Sheet]
FILE NAME: c:\bms\stl\sch-pw\petro.kravets\0140571\3993-0201-sht4-lighting 09-15.dgn

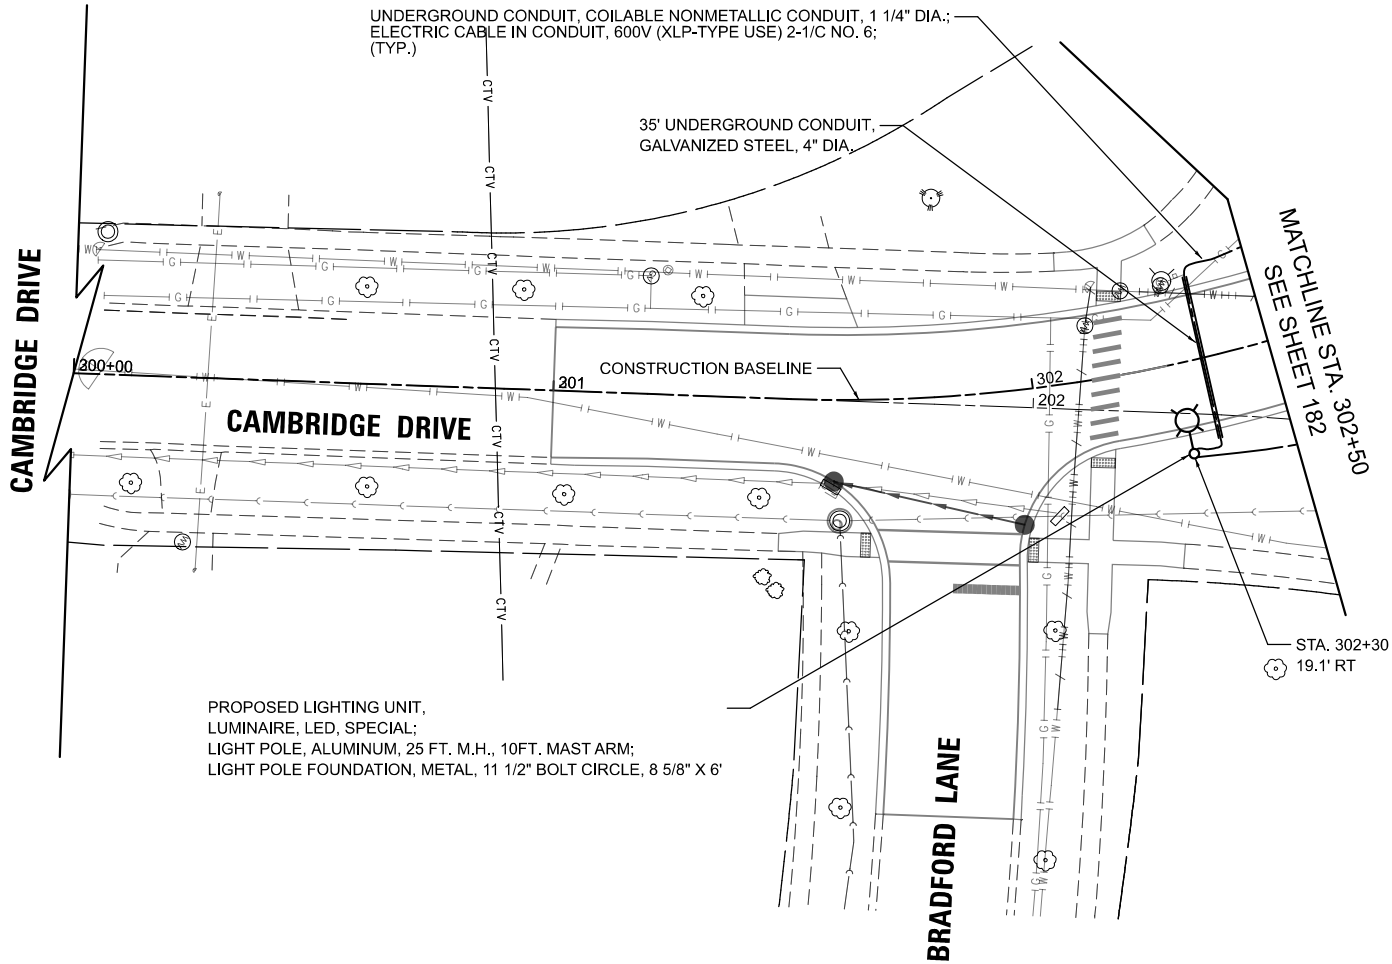

USER NAME	= pk	DESIGNED -	SJC	REVISED -	
		DRAWN -	SJC	REVISED -	
		CHECKED -	DNM	REVISED -	
PLOT DATE	= 12/15/2025	DATE	= 12/12/2025	REVISED -	

STATE OF ILLINOIS
DEPARTMENT OF TRANSPORTATION

CAMBRIDGE DRIVE
LIGHTING PROPOSED PLAN

SCALE: 1"=20'
SHEET 7 OF 8 SHEETS
STA. 300+00.00 TO STA. 302+50.00

MUN. RTE.	SECTION	COUNTY	TOTAL SHEETS	SHEET NO.
4029	23-00146-00-PV	COOK	315	184
CONTRACT NO. 61M26				
		ILLINOIS	FED. AID PROJECT	

MODEL: Braintree - Pr. Wiring [Sheet]
FILE NAME: c:\bms\civiltech\pr\petro.kravets\01405713993-0201-shd-lighting 16.dgn



Two Pierce Place, Suite 1400
Itasca, Illinois 60143
Tel: 630.773.3900
Fax: 630.773.3975
www.civiltechinc.com

USER NAME = pk
PLOT DATE = 12/11/2025

DESIGNED - SJC
DRAWN - SJC
CHECKED - DNM
DATE - 12/12/2025


REVISED -
REVISED -
REVISED -
REVISED -

STATE OF ILLINOIS
DEPARTMENT OF TRANSPORTATION

WEATHERSFIELD WAY
PROPOSED WIRING DIAGRAM

SCALE: 1"=20'
SHEET 8 OF 8 SHEETS
STA. 154+00.00 TO STA. 159+00.00


MUN. RTE.	SECTION	COUNTY	TOTAL SHEETS	SHEET NO.
4029	23-00146-00-PV	COOK	315	185
CONTRACT NO. 61M26				
ILLINOIS FED. AID PROJECT				

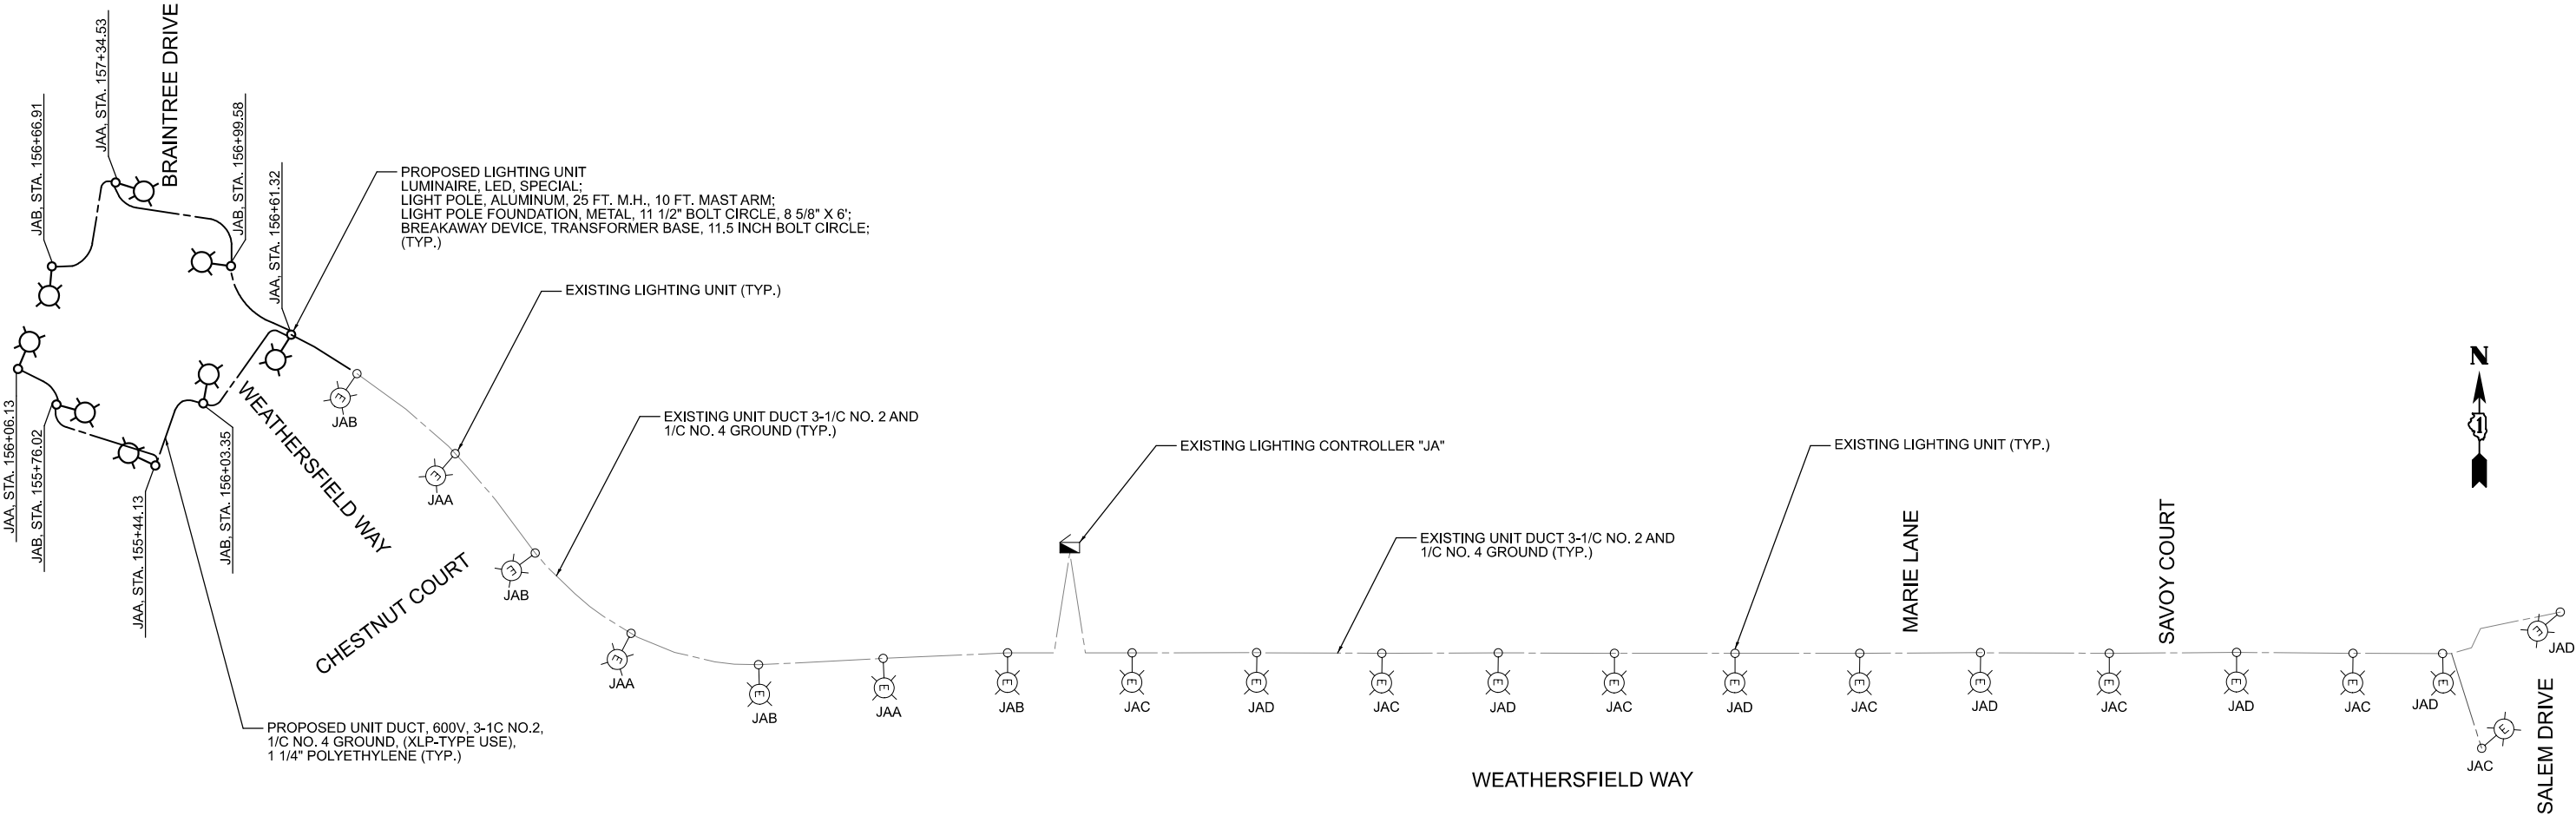

NOTES

1. LIGHTS ON CIRCUIT A AND CIRCUIT C ARE ON RED WIRE
2. LIGHTS ON CIRCUIT B AND CIRCUIT D ARE ON BLACK WIRE

MODEL: Sheet-01 [Sheet]
FILE NAME: c:\bms\ch\lch-pw\patro.kravets\0140571\3993-0201-shH-lighting 17-19.dgn

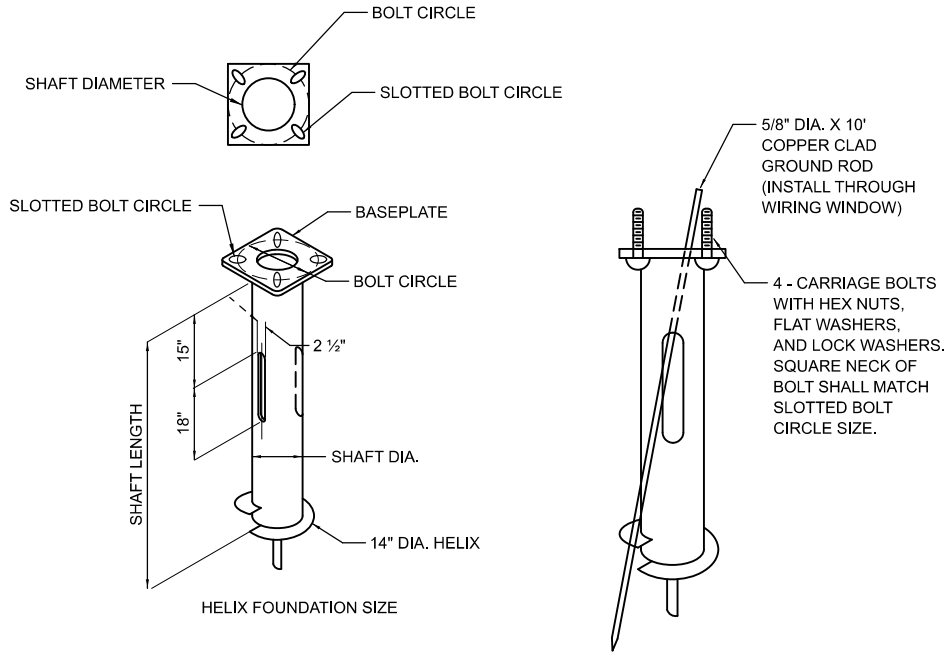

POLE MOUNTING HEIGHT	BOLT CIRCLE	SHAFT DIAMETER	SHAFT LENGTH	BASEPLATE
30 FT.	11½"	8¾"	6 FT.	12" X 12" X 1"
31 FT. - 35 FT.	11½"	8¾"	6 FT.	12" X 12" X 1"
36 FT. - 40 FT.	15"	8¾"	6 FT.	15" X 15" X 1¼"
41 FT. - 45 FT.	15"	8¾"	6 FT.	15" X 15" X 1¼"
46 FT. - 50 FT.	15"	10"	8 FT.	15" X 15" X 1¼"

NOTES FOR METAL FOUNDATION

1.

METAL FOUNDATION SHALL BE THE FOUNDATION USED FOR ALL LIGHTING AND DECORATIVE LIGHTING UNITS UNLESS CONDITIONS IN THE FIELD MAKES IT IMPOSSIBLE TO USE METAL FOUNDATIONS, THEN AN OFFSET FOUNDATION SHALL BE USED WITH ENGINEER APPROVAL.
2.

ALL MATERIAL SHALL BE GALVANIZED ACCORDING TO AASHTO M111, UNLESS OTHERWISE SPECIFIED.
3.

ALL WELDS SHALL BE CONTINUOUS AND NOT LESS THAN ¼" FILLET WELDS. THE WELDED FOUNDATION SHALL BE CAPABLE OF WITHSTANDING 10,000 FT/LBS OF INSTALLATION TORQUE APPLIED ABOUT THE AXIS OF THE FOUNDATION.
4.

FABRICATE TWO SLOTS IN THE SHAFT AT 180 DEGREES FOR UNIT DUCTS AND CABLES ENTERING AND LEAVING THE POLE FOUNDATION.
5.

TOP PLATE SHALL BE PERMANENTLY MARKED WITH THE CABLING SLOT LOCATIONS.
6.

HELIX FOUNDATION SHALL BE INSTALLED VERTICAL AND THE BASEPLATE SHALL BE IN LEVEL. THE BREAKAWAY COUPLINGS AND HARDWARE SHALL NOT BE USED TO ALIGN THE POLE INSTALLATION.
7.

THE CABLE TRENCH SHALL BE BACKFILLED AND FIRMLY COMPACTED BEFORE THE INSTALLATION OF THE LIGHT POLE.
8.

THE CONTRACTOR SHALL COORDINATE EXTENSION OF ANCHOR BOLTS ABOVE TOP OF THE BASEPLATE WITH THE BREAKAWAY DEVICE MANUFACTURER'S REQUIREMENTS.
9.

ANY VOIDS WITHIN THE METAL FOUNDATION SHALL BE FILLED WITH SAND.
10.

METAL FOUNDATIONS SHALL BE INSTALLED IN UNDISTURBED SOIL. PREDRILLING A PILOT HOLE AND/OR BACKFILLING AROUND THE FOUNDATION IS NOT ALLOWED.
11.

GROUND ROD, 5/8" DIA. x 10', THROUGH FOUNDATION WILL BE REQUIRED AND INCLUDED ON ALL LIGHT POLE FOUNDATIONS INCLUDING METAL FOUNDATIONS.
12.

THE METAL FOUNDATION SHALL NOT BE INSTALLED TO A TORQUE WHICH EXCEEDS THE MANUFACTURER'S MAXIMUM TORQUE RATING NOR SHALL IT BE INSTALLED TO AN INSTALLATION TORQUE VALUE OF LESS THAN 3,500 FT LB. METAL FOUNDATIONS THAT ARE NOT INSTALLED TO FULL INSTALLATION DEPTH OR DO NOT ACHIEVE THE MINIMUM INSTALLATION TORQUE SHALL BE REMOVED AND REPLACED WITH A CONCRETE FOUNDATION AT NO ADDITIONAL COST.
13.

THE BASEPLATE SHALL BE PERPENDICULAR TO THE SHAFT AXIS (∠ 1°) AND THE HOLE CENTERLINE SHALL BE CONCENTRIC (∠ 0.188) TO THE SHAFT AXIS.
14.

THE PILOT POINT AND SHAFT AXIS SHALL BE CONCENTRIC (∠ 0.125) AND IN LINE (∠ 2°).
15.

THE BASEPLATE SHALL BE STAMPED WITH THE MANUFACTURERS NAME AND DATE OF MANUFACTURE.
16.

ALL MATERIAL IS TO BE NEW, UNUSED AND MILL TRACEABLE MEETING THE FOLLOWING SPECIFICATIONS:
- BASE PLATE:

AASHTO M 270M, GRADE 36 (M270M, GRADE 250)
- SHAFT:

ASTM A 252 - (LATEST REVISION) GRADE 2, (PHOSPHOROUS 0.04% MAXIMUM, SULFUR 0.05% MAXIMUM)
- HELIX SCREW:

AASHTO M 183 (ASTM A 635) (LATEST REVISION)
- PILOT POINT:

AASHTO M 270 (ASTM A 575) (LATEST REVISION)
- ANCHOR RODS/STUDS:

AASHTO M 314 (ASTM F 1554) (LATEST REVISION)
- HEXAGON NUTS:

AASHTO M 291M (ASTM A 563) GRADE DH, OR AASHTO M 292 (ASTM A 194) GRADE 2H (LATEST REVISION)
- WASHERS:

AASHTO M 293 (ASTM F 436) (LATEST REVISION)

POLE FOUNDATION METAL

HELIX MUST BE FORMED BY MATCHING METAL DIE
(SIDE VIEW OF TRUE HELICAL FORM)

STATE OF ILLINOIS
DEPARTMENT OF TRANSPORTATION


BRAINTREE DRIVE
LIGHTING DETAILS

SCALE: N.T.S. SHEET 1 OF 3 SHEETS STA. TO STA.


MUN RTE.	SECTION	COUNTY	TOTAL SHEETS	SHEET NO.
4029	23-00146-00-PV	COOK	315	186
CONTRACT NO. 61M26				
ILLINOIS FED. AID PROJECT				

NOTES:

- 1. IN GRASS COVERED AREAS, THE BACKFILL MAY BE COMPACTED EARTH.
- 2. TRENCHES WITHIN 2' OF PROPOSED OR EXISTING STREETS, DRIVEWAYS, OR SIDEWALKS WILL BE BACKFILLED WITH COMPACTED FA-6 SAND OR LIMESTONE SCREENINGS.
- 3. WARNING TAPE WILL BE RED WITH BLACK LETTERING TO READ "CAUTION - ELECTRIC LINE BURIED BELOW".
- 4. ALL GRASS COVERED AREAS DISTURBED DURING CONSTRUCTION WILL BE RESTORED WITH 4" OF TOPSOIL AND SOD.

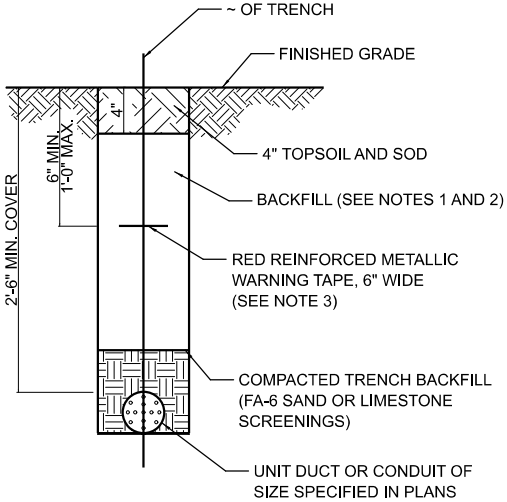


TYPICAL TRENCH CROSS SECTION

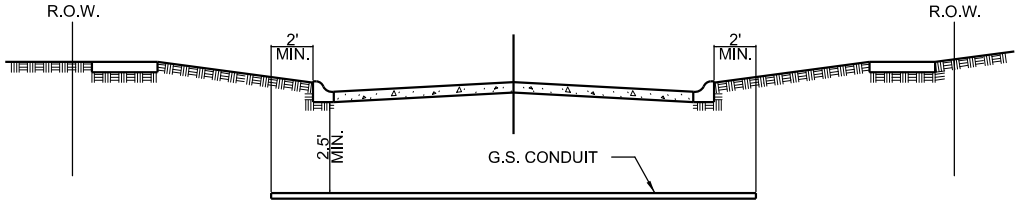


NOTES

- 1. PAVEMENT INCLUDES ROADS, DRIVEWAYS, SIDEWALKS, AND BIKE PATHS.
- 2. CONDUIT SHALL BE HEAVY WALL RIGID GALVANIZED STEEL CONDUIT, MINIMUM 2" DIAMETER.
- 3. CONDUIT SHALL EXTEND A MINIMUM OF 2 FT. BEYOND BACK OF CURB OR EDGE OF PAVEMENT.
- 4. CONDUIT SHALL BE A MINIMUM OF 2.5 FT. BELOW BOTTOM OF PAVEMENT.


ELECTRICAL CONDUIT UNDER PAVEMENT

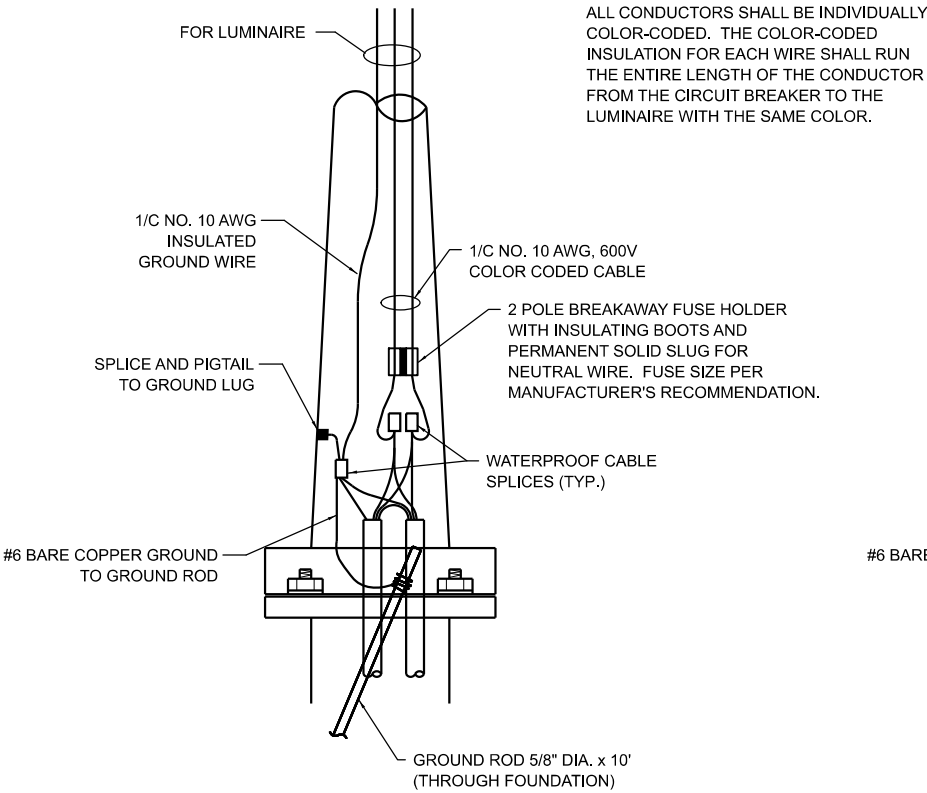

ALL CONDUCTORS SHALL BE INDIVIDUALLY COLOR-CODED. THE COLOR-CODED INSULATION FOR EACH WIRE SHALL RUN THE ENTIRE LENGTH OF THE CONDUCTOR FROM THE CIRCUIT BREAKER TO THE LUMINAIRE WITH THE SAME COLOR.

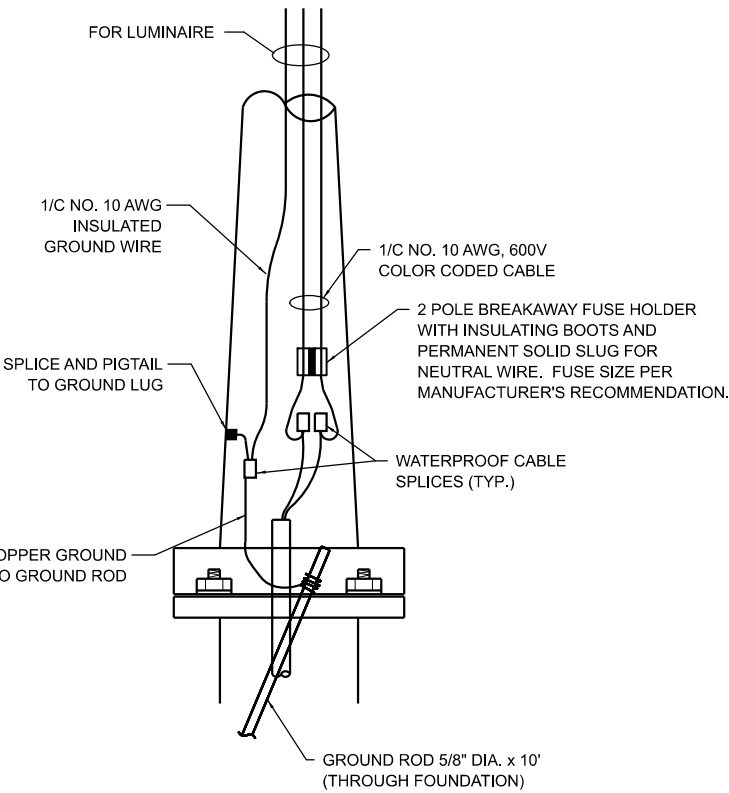

ROADWAY POLE HANDHOLE WIRING DIAGRAM

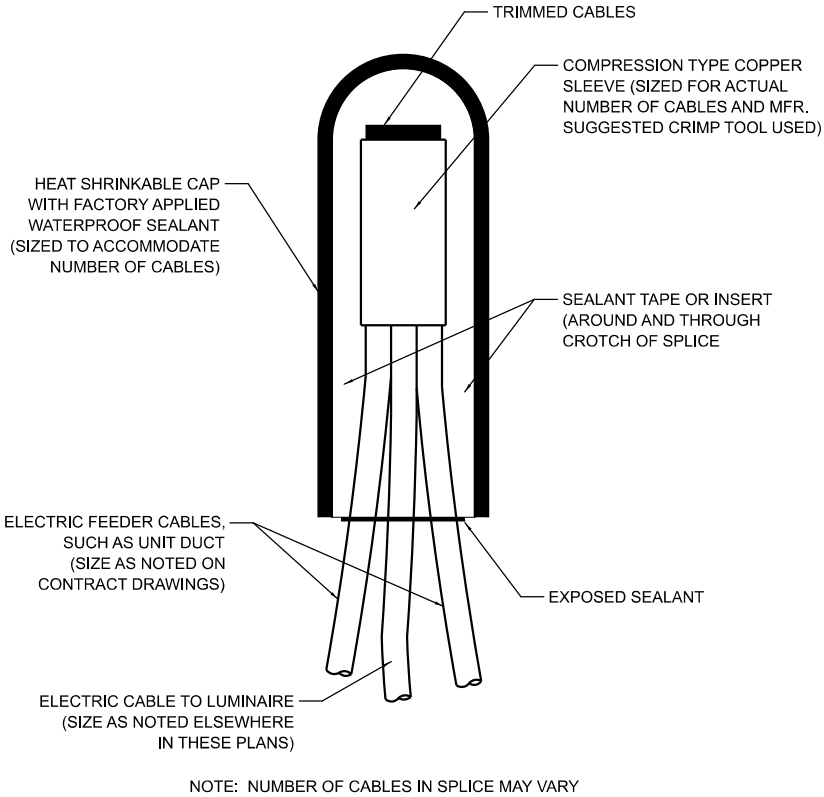

NOTE: NUMBER OF CABLES IN SPLICE MAY VARY

SPLICING ELECTRIC CABLES BASIC MATERIALS AND METHODS

MODEL: Sheet-02 [Sheet]
FILE NAME: c:\bms\sch\lch-pw\patro.kravets\0140571\3993-0201-shh-lighting 17-19.dgn


USER NAME = pk	DESIGNED - SJC	REVISED -
	DRAWN - SJC	REVISED -
	CHECKED - DNM	REVISED -
PLOT DATE = 12/15/2025	DATE - 12/12/2025	REVISED -

STATE OF ILLINOIS
DEPARTMENT OF TRANSPORTATION

BRAINTREE DRIVE
LIGHTING DETAILS

SCALE: N.T.S. SHEET 2 OF 3 SHEETS STA. TO STA.

MUN RTE.	SECTION	COUNTY	TOTAL SHEETS	SHEET NO.
4029	23-00146-00-PV	COOK	315	187
CONTRACT NO. 61M26				
ILLINOIS FED. AID PROJECT				

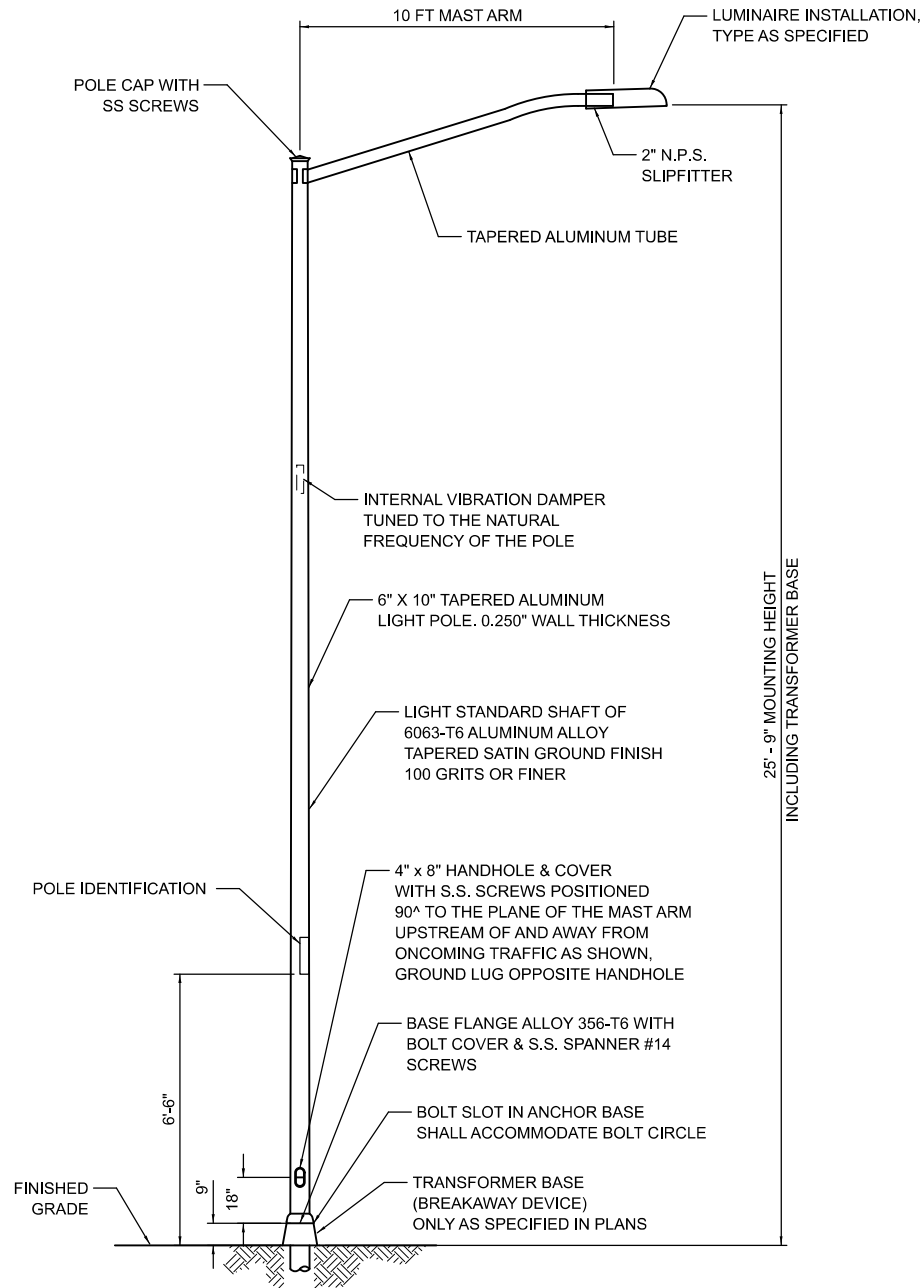


NOTES:

- HEAT TREATMENT SHALL BE APPLIED AFTER WELDING.
- DESIGN AND FABRICATION OF THE POLE SHAFT, ARMS, TENONS, AND ATTACHMENTS SHALL BE ACCORDING TO AASHTO "LRFD SPECIFICATIONS FOR STRUCTURAL SUPPORTS FOR HIGHWAY SIGNS, LUMINAIRES AND TRAFFIC SIGNALS" CURRENT AT THE TIME THE PROJECT IS ADVERTISED.
- POLES AND ARMS SHALL BE BUILT TO TOLERANCES THAT WILL ALLOW CONSISTENT INTERCHANGIBILITY TO FACILITATE REPLACEMENT OF ARMS AND POLES.
- A DECAL COMPLYING WITH THE ANSI STANDARD SHALL BE PERMANENTLY ATTACHED TO THE LUMINAIRE AT THE FACTORY. THE DECK SHALL ALLOW A VIEWER AT GROUND LEVEL TO IDENTIFY THE WATTAGE AND LUMINAIRE PHOTOMETRIC DISTRIBUTION.

LIGHTING UNIT

(NOT TO SCALE)

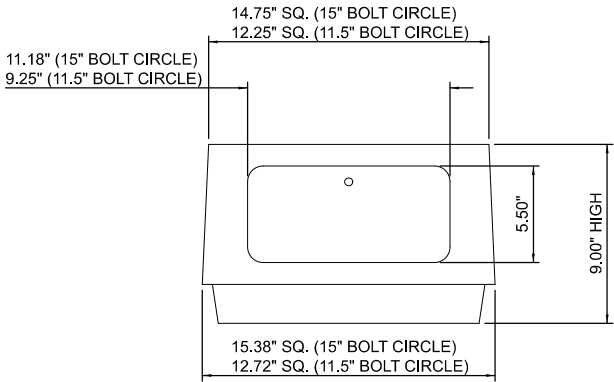


NOTES:


- DOORS: ALUMINUM ONLY.
- HARDWARE: CARRIAGE BOLTS SHALL BE USED WITH FLAT WASHER, LOCK WASHER, AND NUTS. NO THREADED ROD ALLOWED.
- GROUNDING: AREA WHERE THE GROUND WIRE ATTACHES TO TRANSFORMER BASE MUST BE SCRATCHED TO ENSURE EFFECTIVE BONDING.

TRANSFORMER BASE
(BREAKAWAY DEVICE)

(MEET LATEST AASHTO REQUIREMENTS)

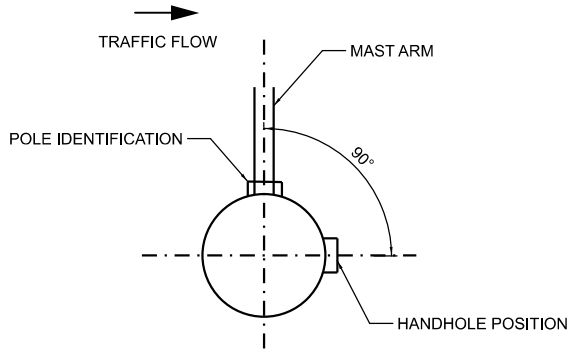

POSITION OF HANDHOLE
AND POLE IDENTIFICATION

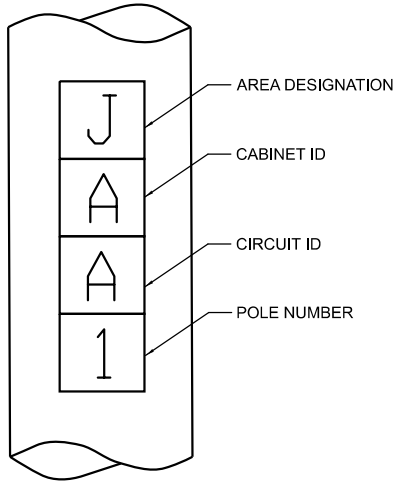

NOTES:

- 4" HIGH WHITE LETTERS ON RED, PRESSURE SENSITIVE AND REFLECTIVE BACKGROUND. ONE PIECE STICKER PER CHARACTER 4" x 4 1/2"
- FONT TO BE T2000 HWYC.



POLE IDENTIFICATION

MODEL: Sheet-03 [Sheet]
FILE NAME: c:\bms\ch\lch-pw\patro.kravets\0140571\3993-0201-shd-lighting 17-19.dgn

	USER NAME = pk		DESIGNED - SJC	REVISED -	STATE OF ILLINOIS DEPARTMENT OF TRANSPORTATION	BRAINTREE DRIVE LIGHTING DETAILS				MUN RTE.	SECTION	COUNTY	TOTAL SHEETS	SHEET NO.
			DRAWN - SJC	REVISED -						4029	23-00146-00-PV	COOK	315	188
			CHECKED - DNM	REVISED -						CONTRACT NO. 61M26				
	PLOT DATE = 12/15/2025		DATE - 12/12/2025	REVISED -		SCALE: N.T.S.	SHEET 3	OF 3	SHEETS	STA.	TO STA.	ILLINOIS FED. AID PROJECT		

MODEL: Sheet-01 [Sheet]
FILE NAME: c:\bms\ch\ch-pw\patc.kravets\0140573\Construction Details.dgn

AUTOCAD2006

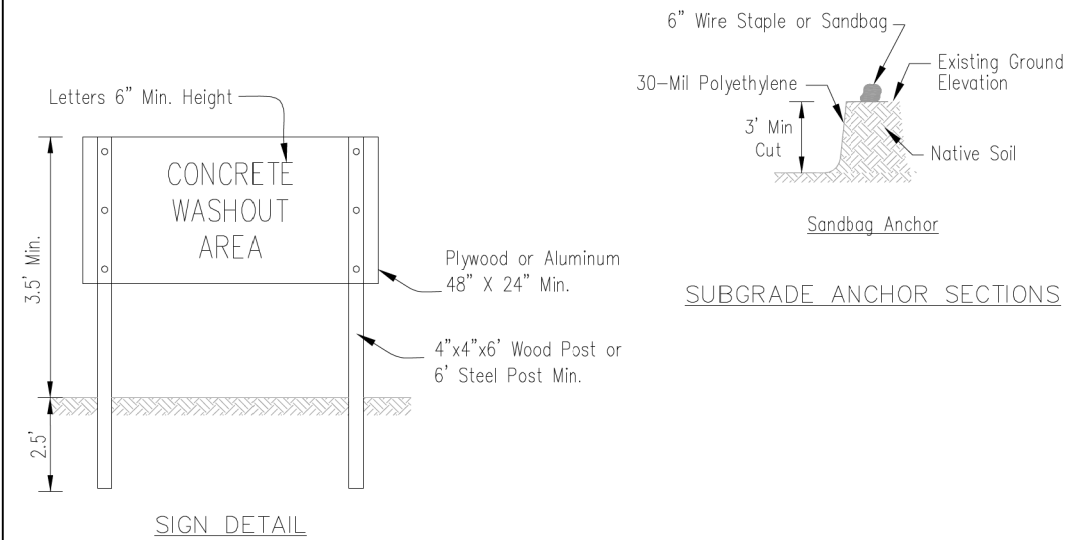
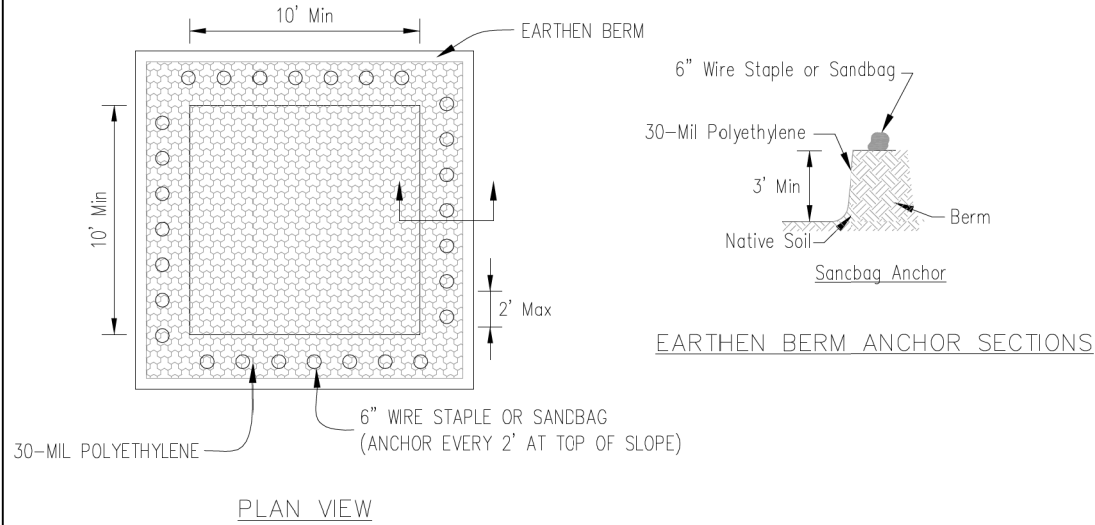


NOTES:

1. Maintaining temporary concrete washout facilities shall include removing and disposing of hardend concrete and/or slurry and returning the facilities to a functional condition.
2. Facility shall be cleaned or reconstructed in a new area once washout becomes two-thirds full.

Sheet 2 of 3	Drawn By JUN-SSA-CT	File No. JUN-SSA-CT	TEMPORARY CONCRETE WASHOUT FACILITY – EARTHEN TYPE	Designed Drawn B. JOHNSON Checked Approved	Date 6/08
--------------	------------------------	------------------------	---	---	--------------

AUTOCAD2006

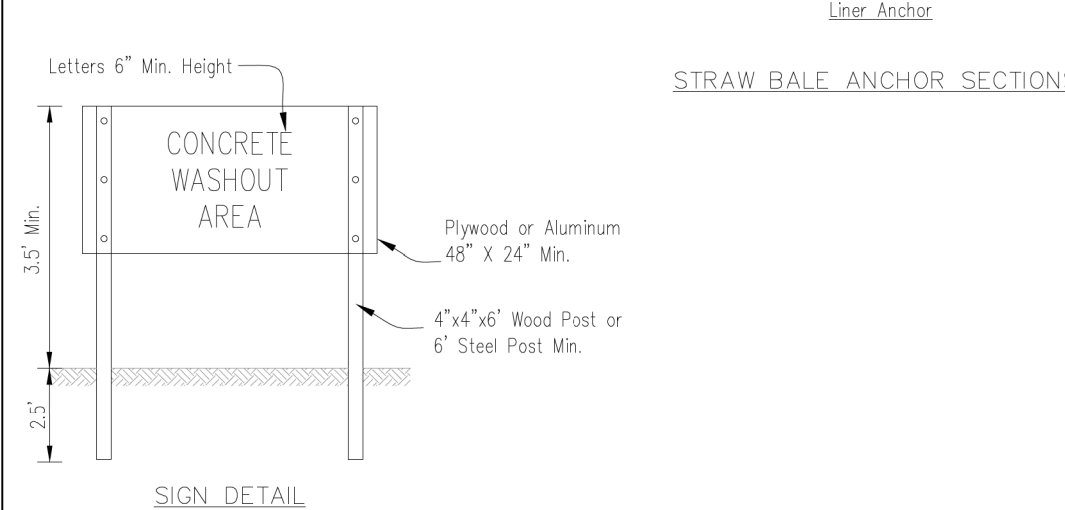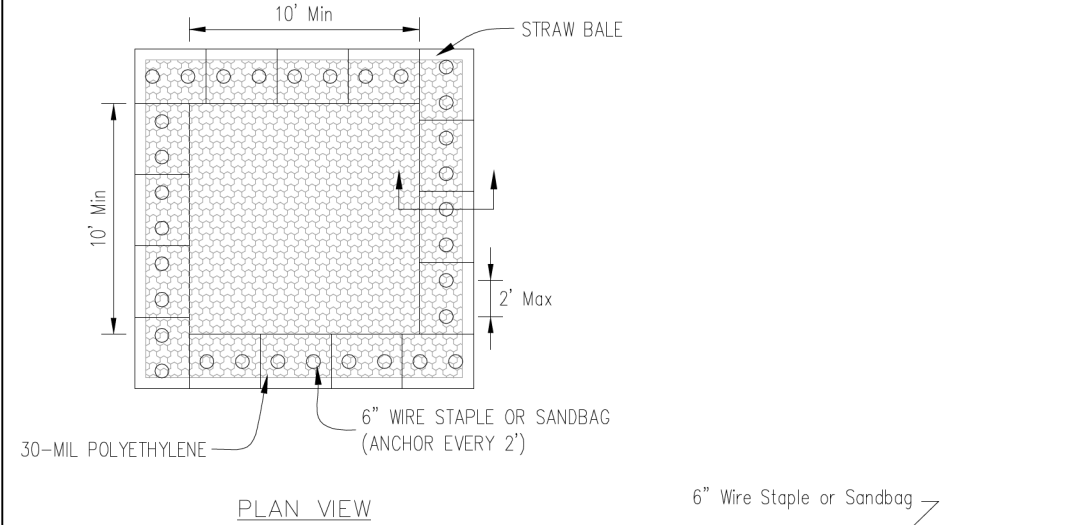

NOTES:

1. Maintaining temporary concrete washout facilities shall include removing and disposing of hardend concrete and/or slurry and returning the facilities to a functional condition.
2. Facility shall be cleaned or reconstructed in a new area once washout becomes two-thirds full.
3. Each straw bale is to be staked in place using (2) 2"x2"x4' wooden stakes.

Sheet 1 of 3	Drawn By JUN-SSA-CT	File No. JUN-SSA-CT	TEMPORARY CONCRETE WASHOUT FACILITY – STRAW BALE	Designed Drawn B. JOHNSON Checked Approved	Date 6/08
--------------	------------------------	------------------------	---	---	--------------

USER NAME	= pk	DESIGNED	-	REVISED	-
		DRAWN	-	REVISED	-
		CHECKED	-	REVISED	-
PLOT DATE	= 12/15/2025	DATE	= 12/12/2025	REVISED	-


STATE OF ILLINOIS
DEPARTMENT OF TRANSPORTATION

BRAINTREE DRIVE
CONSTRUCTION DETAILS


SCALE: N.T.S. SHEET 1 OF 9 SHEETS STA. TO STA.

MUN RTE.	SECTION	COUNTY	TOTAL SHEETS	SHEET NO.
4029	23-00146-00-PV	COOK	315	189
CONTRACT NO. 61M26				
ILLINOIS FED. AID PROJECT				


AUTOCAD2006

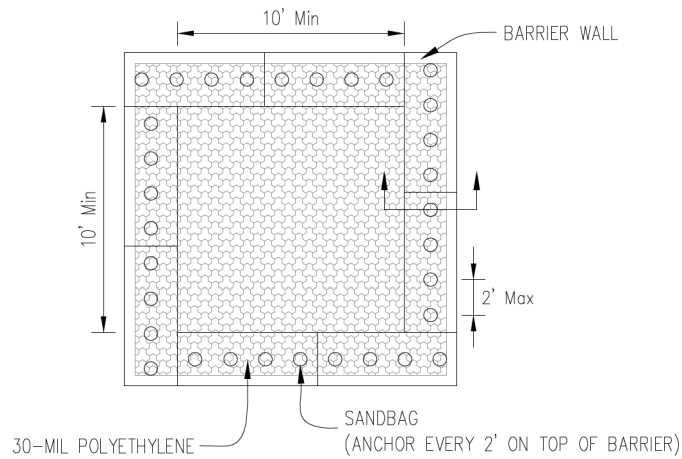

PLAN VIEW

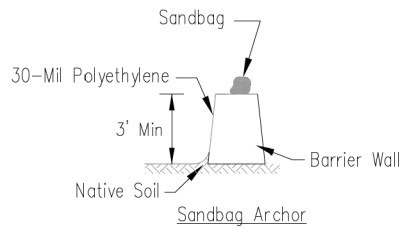

BARRIER WALL ANCHOR SECTION

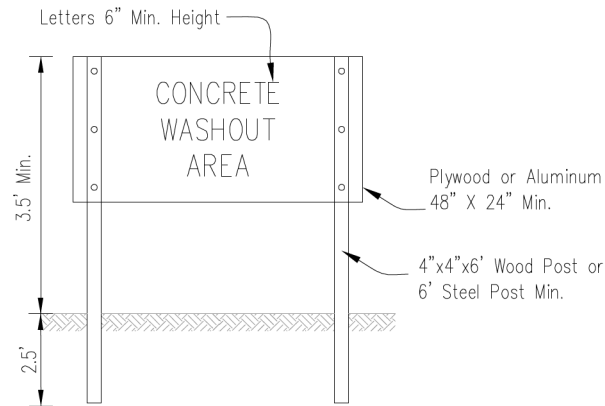



SIGN DETAIL

NOTES:

1. Maintaining temporary concrete washout facilities shall include removing and disposing of hardend concrete and/or slurry and returning the facilities to a functional condition.
2. Facility shall be cleaned or reconstructed in a new area once washout becomes two-thirds full.

Sheet 3 of 3	on Dunes	File No.	TEMPORARY CONCRETE WASHOUT FACILITY – BARRIER WALL	Designed	Date
	MBP55-WN			Drawn B. JOHNSON	6/08
				Checked	
				Approved	

INLET PROTECTION – PAVED AREAS DROP-IN PROTECTION

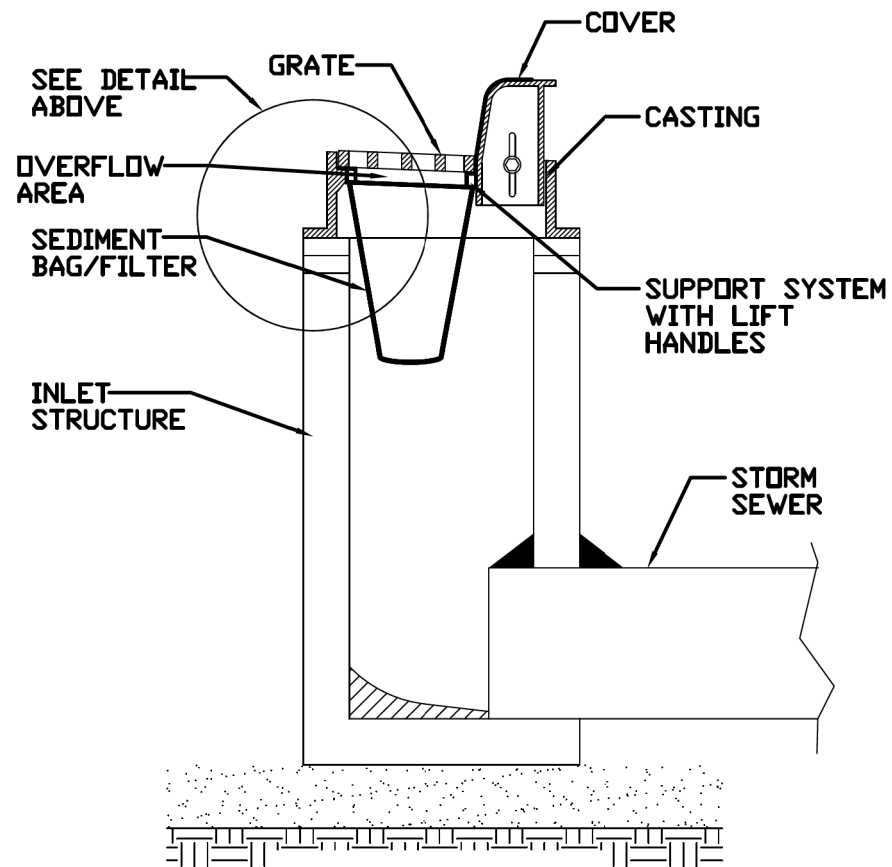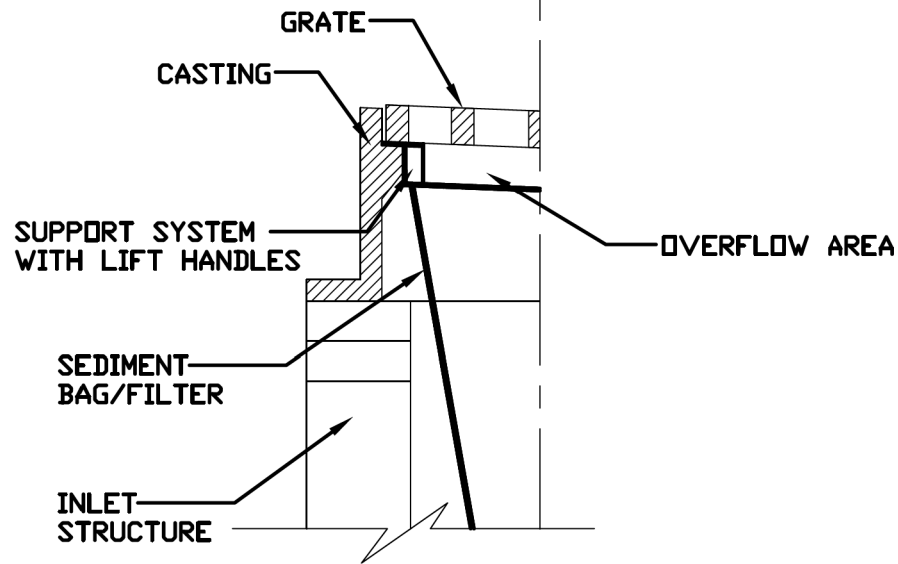

REFERENCE

Project _____ Date _____
Designed _____ Date _____
Checked _____ Date _____
Approved _____ Date _____



STANDARD DWG. NO.

IUM-561D

SHEET 1 OF 1

DATE 01-11-11

MODEL: Sheet-02 [Sheet]
FILE NAME: c:\bms\sch\itc-pw\patro.kravets\0140573\Construction Details.dgn





USER NAME = pk	DESIGNED -	REVISED -
	DRAWN -	REVISED -
	CHECKED -	REVISED -
PLOT DATE = 12/15/2025	DATE - 12/12/2025	REVISED -

STATE OF ILLINOIS
DEPARTMENT OF TRANSPORTATION

BRAINTREE DRIVE
CONSTRUCTION DETAILS

SCALE: N.T.S. SHEET 2 OF 9 SHEETS STA. TO STA.

MUN. RTE.	SECTION	COUNTY	TOTAL SHEETS	SHEET NO.
4029	23-00146-00-PV	COOK	315	190
CONTRACT NO. 61M26				
ILLINOIS FED. AID PROJECT				

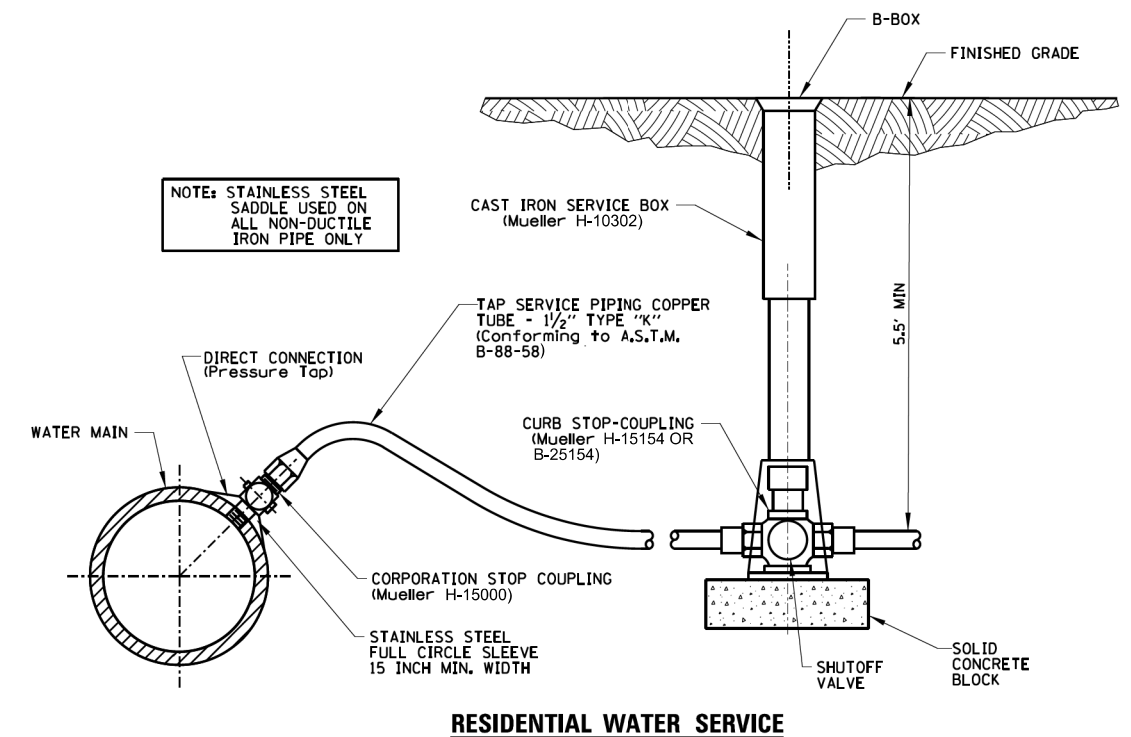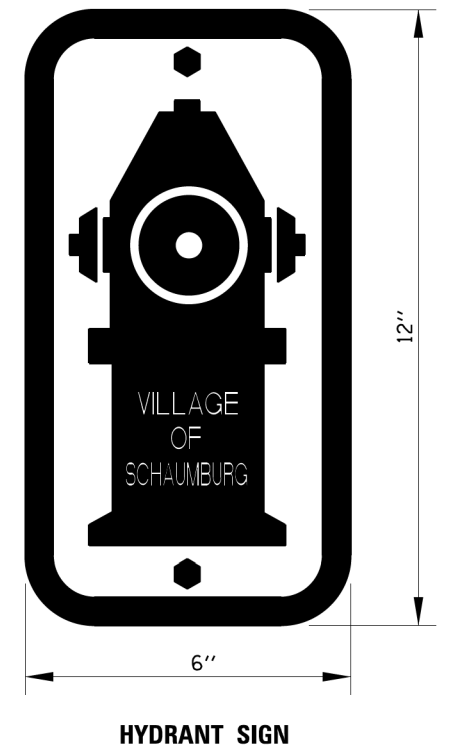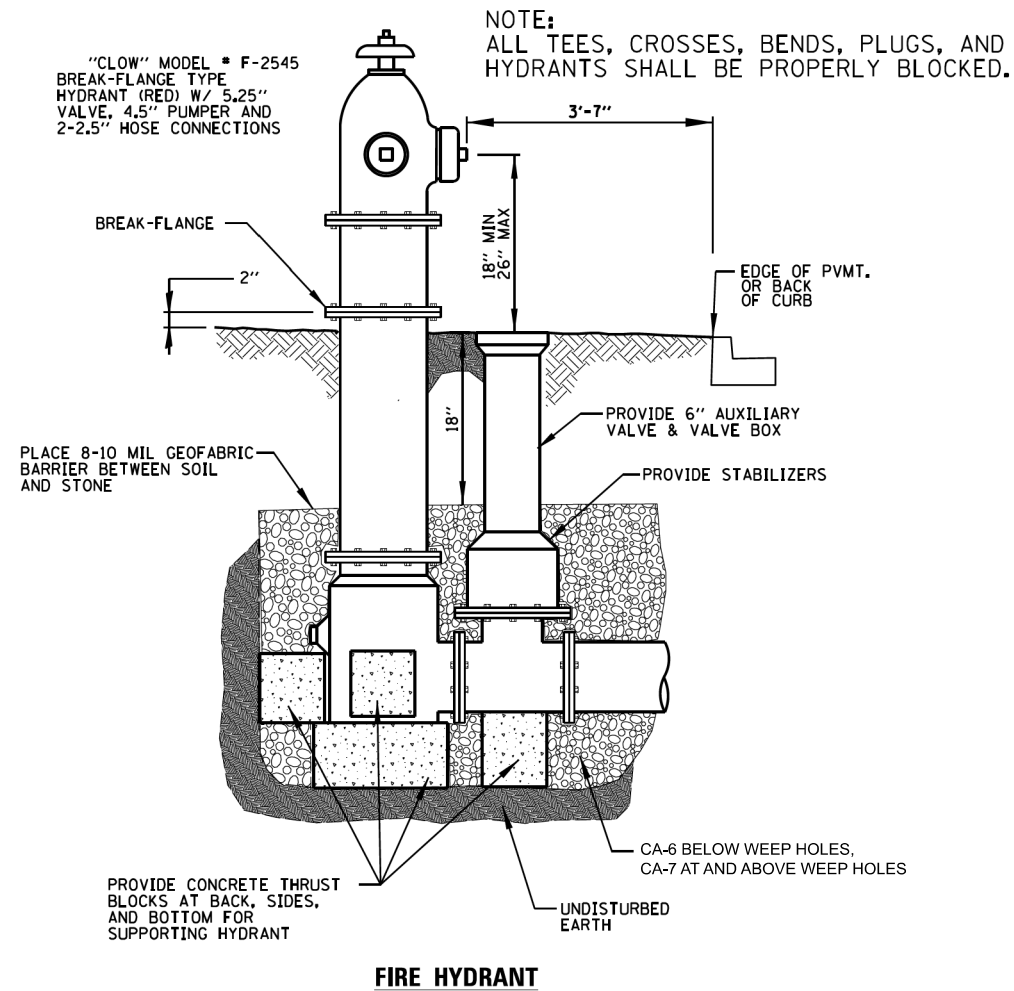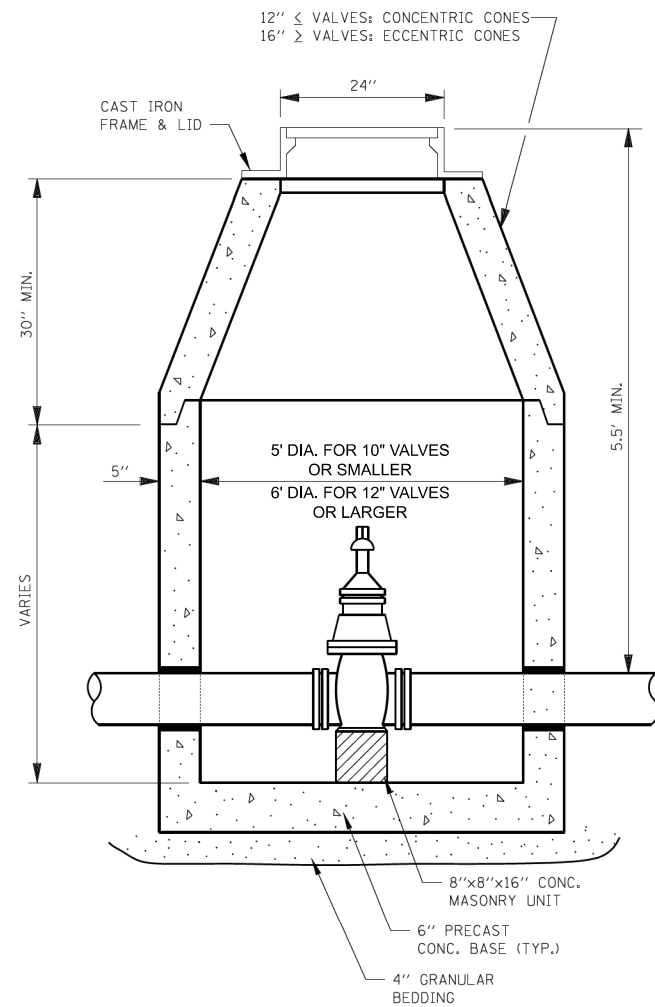

MODEL: Sheet-04 [Sheet]
FILE NAME: c:\bms\sch\ch-pw\patro.kravets\0140573\Construction Details.dgn

PROPOSED SEWER LINE WITH 18" MINIMUM VERTICAL SEPARATION ABOVE EXISTING WATER MAIN

GUIDELINES

- IF SELECT GRANULAR BACKFILL EXISTS: REMOVE WITHIN WIDTH OF PROPOSED SEWER TRENCH AND REPLACE WITH SELECT EXCAVATED MATERIAL (CLASS IV) AND COMPACT
- OMIT SELECT GRANULAR EMBEDMENT AND GRANULAR BACKFILL TO ONE (1) FOOT OVER TOP OF SEWER AND USE SELECT EXCAVATED MATERIAL (CLASS IV) AND COMPACT THE LENGTH OF "L" FEET.
- A) CONSTRUCT "L" FEET OF PROPOSED SEWER OF WATER MAIN MATERIAL AND PRESSURE TEST, OR;
B) USE "L" FEET OF WATER MAIN MATERIAL FOR CASING OF PROPOSED SEWER AND SEAL ENDS OF CASING.

NOTE: "S" THE LENGTH NECESSARY TO PROVIDE 10 FEET OF SEPARATION AS MEASURED PERPENDICULAR TO THE EXISTING WATER MAIN

*BASED ON STANDARD SPECIFICATIONS FOR WATER AND SEWER MAIN CONSTRUCTION IN ILLINOIS.

PROPOSED SEWER LINE BELOW EXISTING WATER MAIN WITH LESS THAN 18" MINIMUM VERTICAL SEPARATION

GUIDELINES

- OMIT SELECT GRANULAR EMBEDMENT AND GRANULAR BACKFILL TO ONE (1) FOOT OVER TOP OF SEWER AND USE SELECT EXCAVATED MATERIAL (CLASS IV) AND COMPACT FOR "S" FEET ON EACH SIDE OF WATER MAIN.
- A) CONSTRUCT "L" FEET OF PROPOSED SEWER OF WATER MAIN MATERIAL AND PRESSURE TEST, OR;
B) USE "L" FEET OF WATER MAIN MATERIAL FOR CASING OF PROPOSED SEWER AND SEAL ENDS OF CASING.
- PROVIDE ADEQUATE SUPPORT FOR EXISTING WATER MAIN TO PREVENT DAMAGE DUE TO SETTLEMENT OF SEWER TRENCH

NOTE: "S" THE LENGTH NECESSARY TO PROVIDE 10 FEET OF SEPARATION AS MEASURED PERPENDICULAR TO THE EXISTING WATER MAIN

*BASED ON STANDARD SPECIFICATIONS FOR WATER AND SEWER MAIN CONSTRUCTION IN ILLINOIS.

PROPOSED WATER MAIN ABOVE EXISTING SEWER LINE WITH LESS THAN 18" VERTICAL SEPARATION

GUIDELINES

- OMIT SELECT GRANULAR EMBEDMENT AND GRANULAR BACKFILL TO ONE (1) FOOT OVER TOP OF WATER MAIN AND USE SELECT EXCAVATED MATERIAL (CLASS IV) AND COMPACT THE LENGTH OF "L".
- IF SELECT GRANULAR BACKFILL EXISTS, REMOVE WITHIN WIDTH OF EXISTING SEWER LINE TRENCH AND REPLACE WITH SELECT EXCAVATED MATERIAL (CLASS IV) AND COMPACT.
- USE "L" FEET OF WATER MAIN MATERIAL FOR CASING OF PROPOSED WATER MAIN AND SEAL ENDS OF CASING.
- POINT LOADS SHALL NOT BE ALLOWED BETWEEN WATER MAIN CASING AND SEWER

NOTE: "S" THE LENGTH NECESSARY TO PROVIDE 10 FEET OF SEPARATION AS MEASURED PERPENDICULAR TO THE EXISTING SEWER LINE.

*BASED ON STANDARD SPECIFICATIONS FOR WATER AND SEWER MAIN CONSTRUCTION IN ILLINOIS.

PER IEPA, WHEN PROPOSED SEWER (OR WATER) IS LOCATED 10 FEET OR MORE FROM EXISTING WATER (OR SEWER), NO SPECIAL CONSTRUCTION REQUIRED

PROPOSED SEWER LINE BELOW EXISTING WATER MAIN WITH 18" MINIMUM VERTICAL SEPARATION

GUIDELINES

- PROVIDE ADEQUATE SUPPORT FOR EXISTING WATER MAIN TO PREVENT DAMAGE DUE TO SETTLEMENT OF SEWER TRENCH.

*BASED ON STANDARD SPECIFICATIONS FOR WATER AND SEWER MAIN CONSTRUCTION IN ILLINOIS.

PLACEMENT OF WATER MAIN BELOW EXISTING OR PROPOSED SEWER LINE WITH LESS THAN 18" MINIMUM VERTICAL SEPARATION. **NOT ALLOWED.**

NOT ALLOWED*
MUST MAINTAIN 18" VERTICAL SEPARATION

*BASED ON STANDARD SPECIFICATIONS FOR WATER AND SEWER MAIN CONSTRUCTION IN ILLINOIS.

PROPOSED WATER MAIN BELOW EXISTING SEWER LINE WITH 18" MINIMUM VERTICAL SEPARATION

GUIDELINES

- OMIT SELECT GRANULAR EMBEDMENT AND GRANULAR BACKFILL TO ONE (1) FOOT OVER TOP OF WATER MAIN AND USE SELECT EXCAVATED MATERIAL (CLASS IV) AND COMPACT THE LENGTH OF "L".
- IF SELECT GRANULAR BACKFILL EXISTS, REMOVE WITHIN WIDTH OF EXISTING SEWER LINE TRENCH AND REPLACE WITH SELECT EXCAVATED MATERIAL (CLASS IV) AND COMPACT.
- PROVIDE ADEQUATE SUPPORT FOR EXISTING SEWER LINE TO PREVENT DAMAGE DUE TO SETTLEMENT.
- USE "L" FEET OF WATER MAIN MATERIAL FOR CASING OF PROPOSED WATER MAIN AND SEAL ENDS OF CASING.

PLAN VIEW

PER IEPA, WHEN PROPOSED SEWER (OR WATER) IS LOCATED LESS THAN 10 FEET FROM EXISTING WATER (OR SEWER), DETAILS BELOW SHALL APPLY

NOT TO SCALE


USER NAME = pk	DESIGNED -	REVISED -
	DRAWN -	REVISED -
	CHECKED -	REVISED -
PLOT DATE = 12/15/2025	DATE = 12/12/2025	REVISED -

STATE OF ILLINOIS
DEPARTMENT OF TRANSPORTATION

BRAINTREE DRIVE CONSTRUCTION DETAILS			
SCALE: N.T.S.	SHEET 4	OF 9 SHEETS	STA. TO STA.



MUN. RTE.	SECTION	COUNTY	TOTAL SHEETS	SHEET NO.
4029	23-00146-00-PV	COOK	315	192
CONTRACT NO. 61M26				
ILLINOIS FED. AID PROJECT				

MODEL: Sheet-05 [Sheet]
FILE NAME: c:\bms\ch\ch-pw\patro.kravets\0140573\Construction Details.dgn

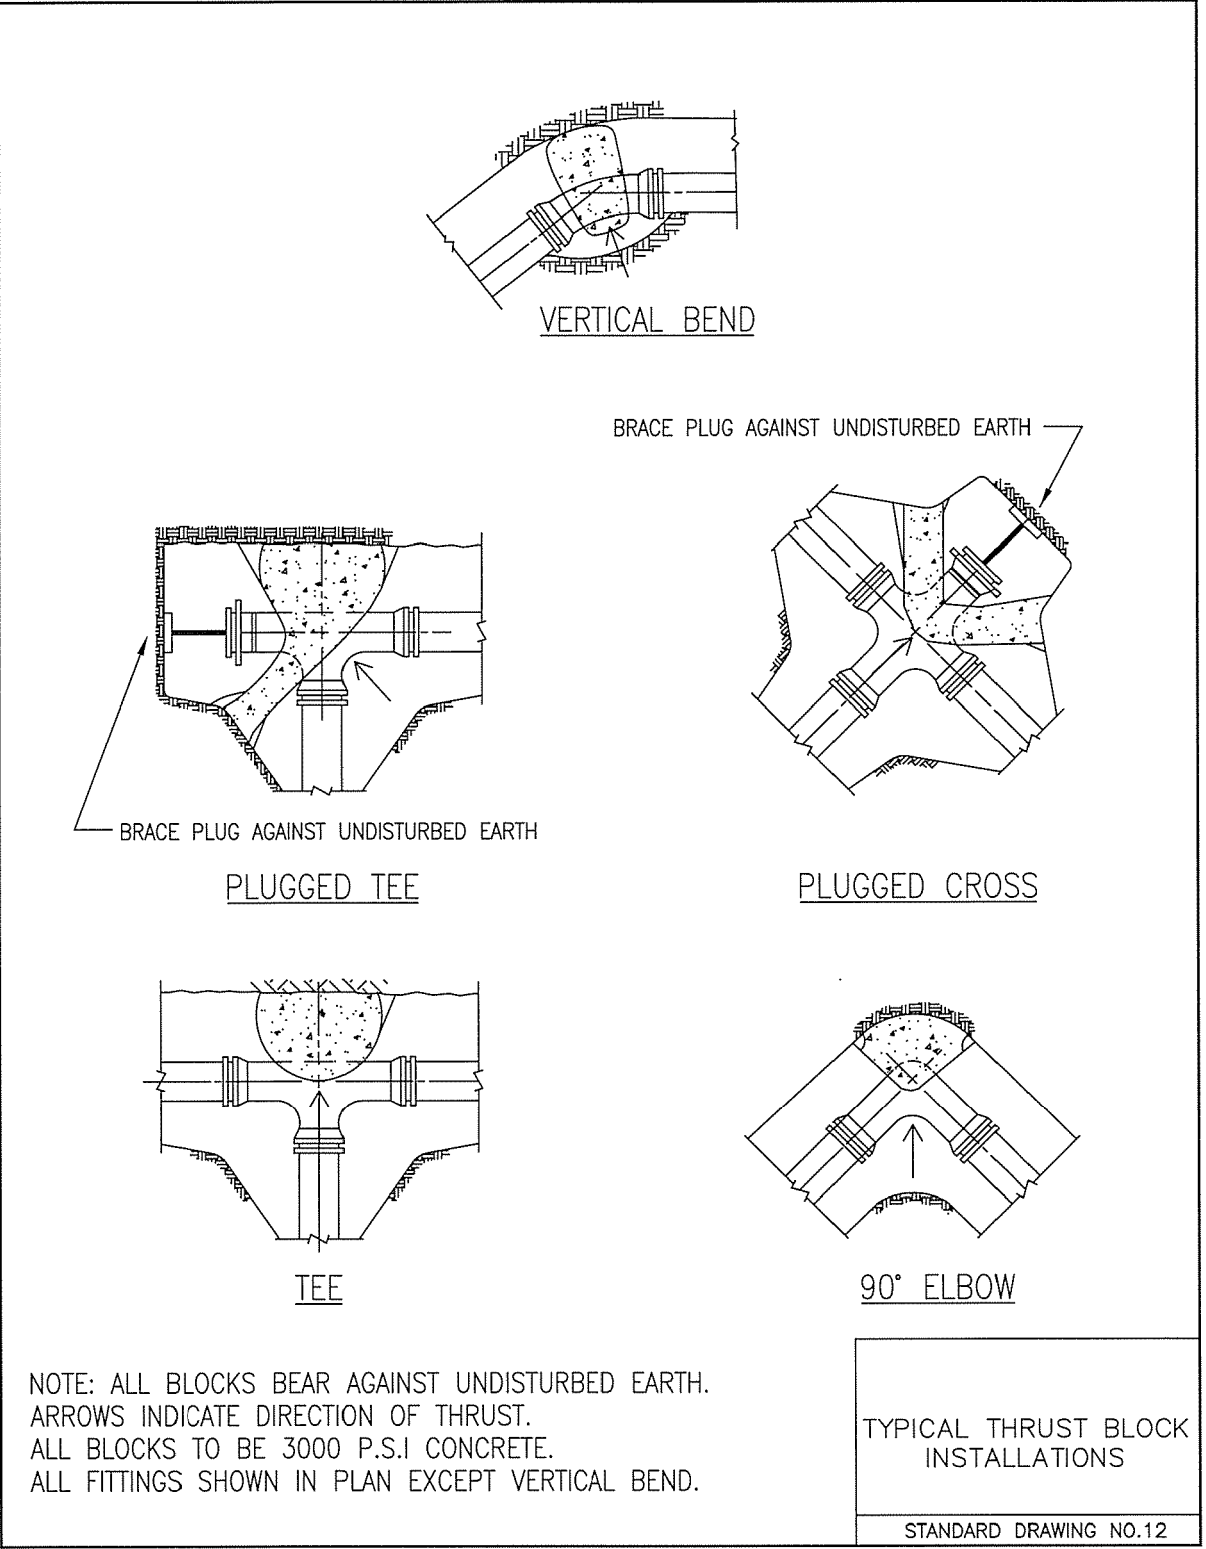

	USER NAME = pk	DESIGNED -	REVISED -	STATE OF ILLINOIS DEPARTMENT OF TRANSPORTATION	BRAINTREE DRIVE CONSTRUCTION DETAILS				MUN RTE.	SECTION	COUNTY	TOTAL SHEETS	SHEET NO.
		DRAWN -	REVISED -						4029	23-00146-00-PV	COOK	315	193
		CHECKED -	REVISED -						CONTRACT NO. 61M26				
	PLOT DATE = 12/15/2025	DATE - 12/12/2025	REVISED -		SCALE: N.T.S.		SHEET 5	OF 9 SHEETS	STA.	TO STA.			
							ILLINOIS FED. AID PROJECT						

MODEL: Sheet-06 [Sheet]
FILE NAME: c:\bms\ch\ch-pw\patro.kravets\0140573\Construction Details.dgn

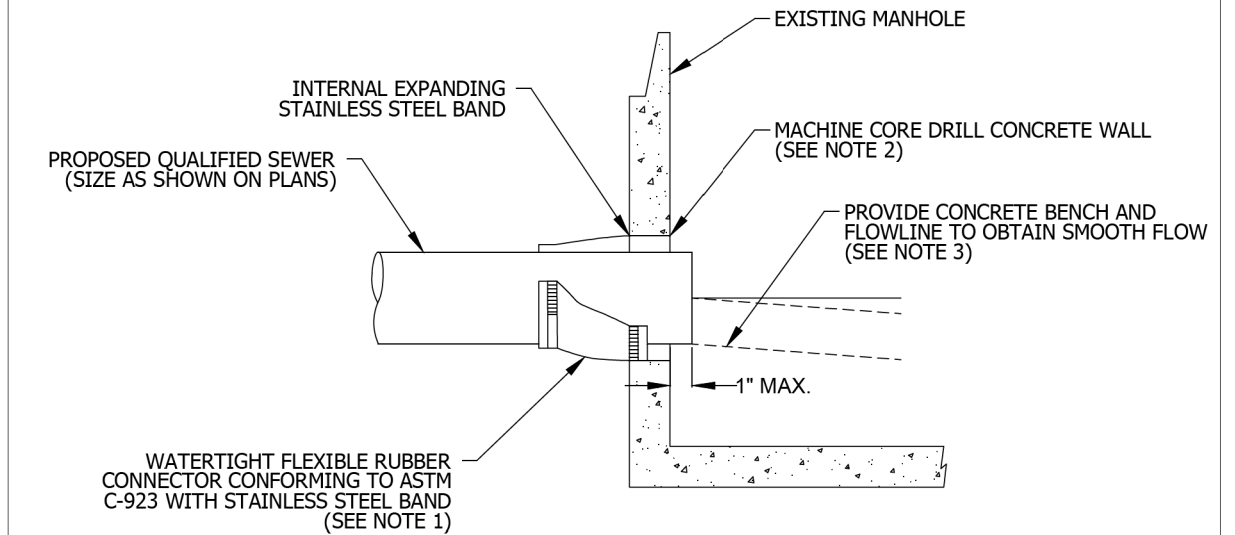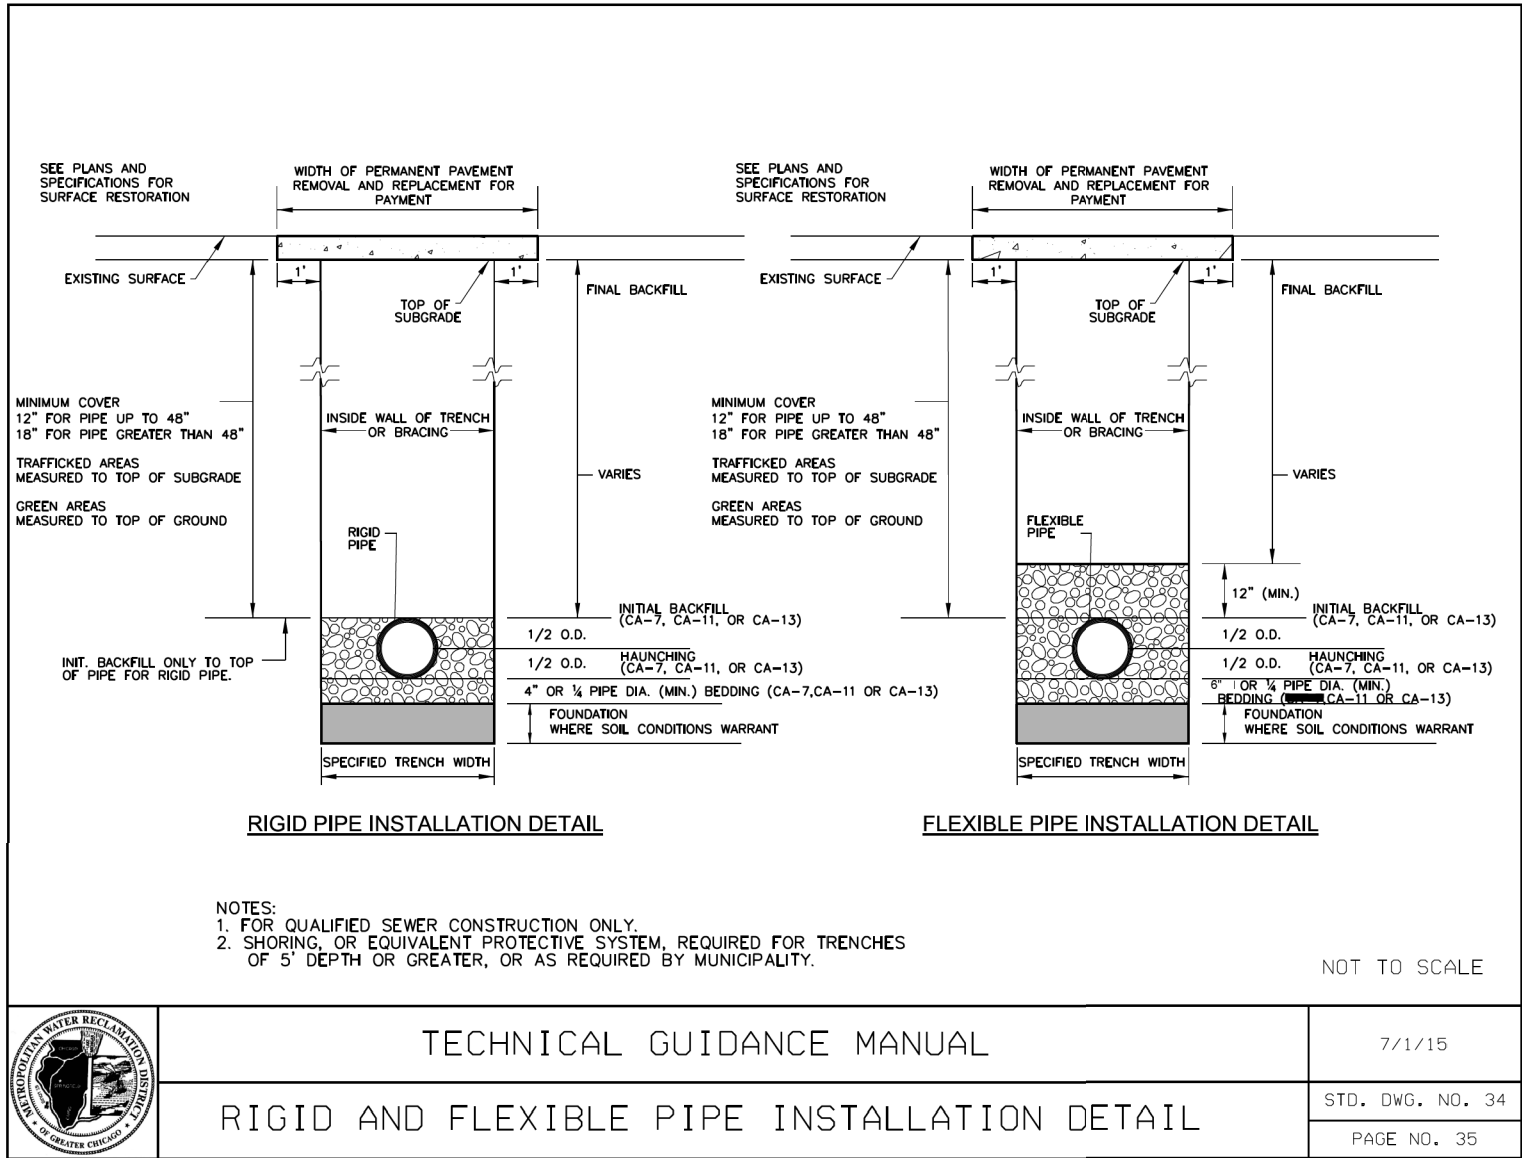

	TECHNICAL GUIDANCE MANUAL		10/02/18
	PIPE TO EXISTING MANHOLE CONNECTION DETAIL		STD. DWG. NO. 42
			PAGE NO. 43


PLOT DATE = 12/15/2025	USER NAME = pk	DESIGNED -	REVISED -
		DRAWN -	REVISED -
		CHECKED -	REVISED -
	DATE = 12/12/2025	REVISED -	

STATE OF ILLINOIS
DEPARTMENT OF TRANSPORTATION


BRAINTREE DRIVE
CONSTRUCTION DETAILS

SCALE: N.T.S. SHEET 6 OF 9 SHEETS STA. TO STA.

MUN. RTE.	SECTION	COUNTY	TOTAL SHEETS	SHEET NO.
4029	23-00146-00-PV	COOK	315	194
CONTRACT NO. 61M26				
ILLINOIS FED. AID PROJECT				

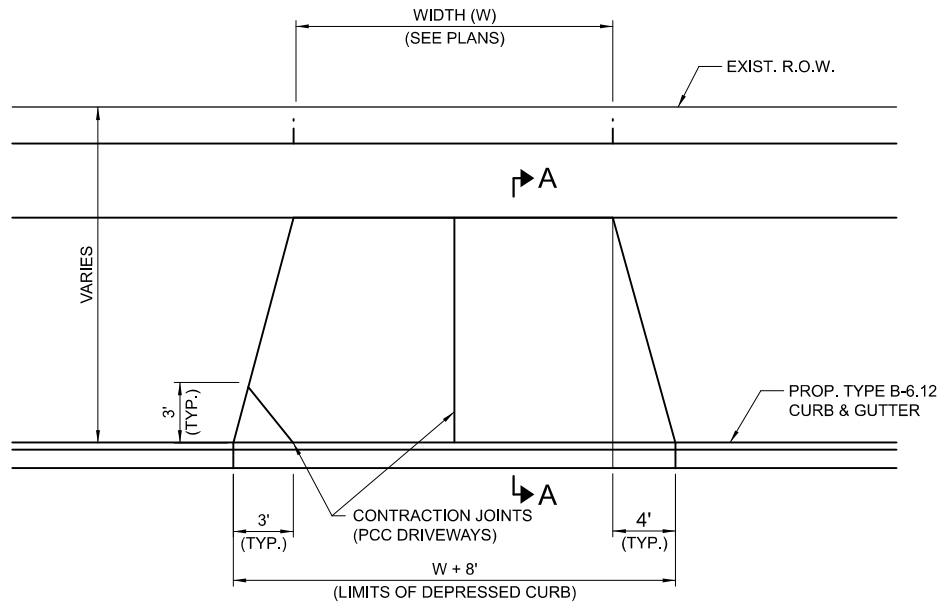


STRAIGHT TAPER PLAN VIEW

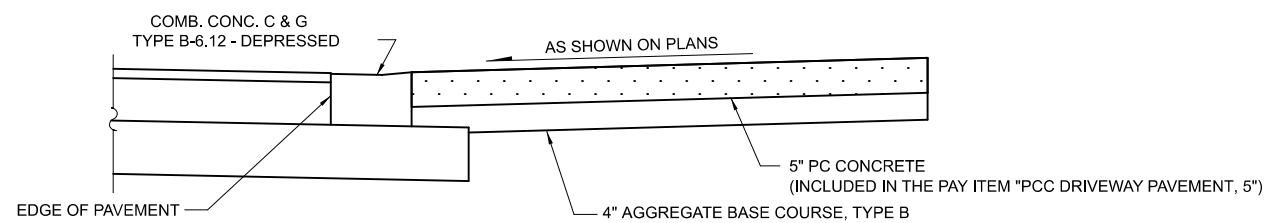

SECTION A-A

PCC RESIDENTIAL DRIVEWAY DETAIL

NOT TO SCALE

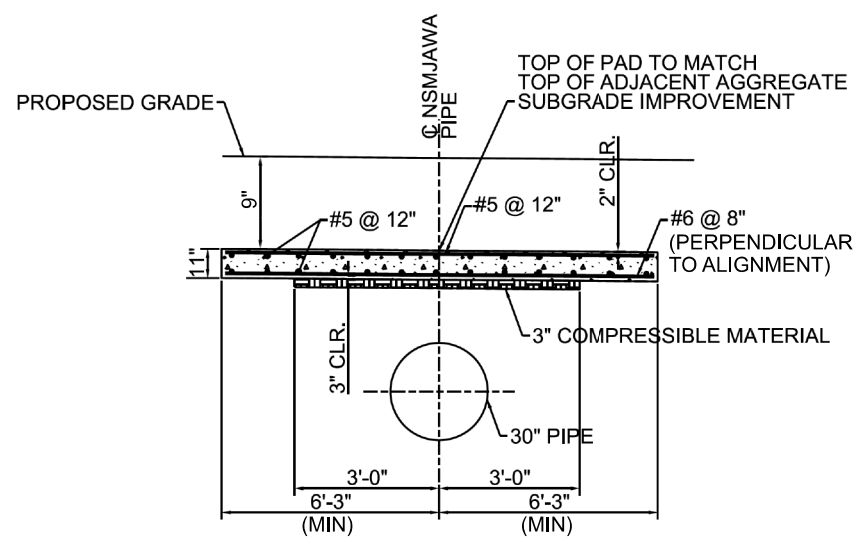

PIPE PROTECTION SLAB DETAIL
NOT TO SCALE

NOTES:

1. MATERIALS:
F_c = 3,500 PSI
REINFORCEMENT BARS SHALL BE GRADE 60 BARS IN ACCORDANCE WITH IDOT STANDARD SPECIFICATIONS FOR ROAD AND BRIDGE CONSTRUCTION.
2. PLACE SLAB IN LIEU OF AGGREGATE SUBGRADE IN PROPOSED PAVEMENT CROSS SECTION. SLAB SHALL BE CURED FOR 7 DAYS IN ACCORDANCE WITH REQUIREMENTS FOR SUBSTRUCTURE IN IDOT STANDARD SPECIFICATIONS FOR ROAD AND BRIDGE CONSTRUCTION PRIOR TO SUBSEQUENT PAVEMENT PLACEMENT.
3. PLACE SLAB AS SHOWN ON THE PLANS.
4. IN AREAS WHERE THE PROPOSED PAVEMENT IS CONSTRUCTED OVER THE EXISTING NSMJAWA WATER MAIN, AND NO STRUCTURAL PROTECTION SLAB IS INSTALLED, CONSTRUCTION LOADS OVER THE EXISTING WATER MAIN SHALL NOT BE GREATER THAN HS-20 LOADINGS.

PROTECTION SLAB FOR
NSMJAWA PIPE

PAID FOR AS "UTILITY PROTECTION PAD"

MODEL: Sheet07 [Sheet]
FILE NAME: c:\bms\schiff-pw\patro.kravets\0140573\Construction Details.dgn





PLOT DATE = 12/15/2025	USER NAME = pk	DESIGNED -	REVISED -
		DRAWN -	REVISED -
		CHECKED -	REVISED -
	DATE = 12/12/2025	DATE - 12/12/2025	REVISED -

STATE OF ILLINOIS
DEPARTMENT OF TRANSPORTATION

BRAINTREE DRIVE
CONSTRUCTION DETAILS

SCALE: N.T.S. SHEET 7 OF 9 SHEETS STA. TO STA.

MUN. RTE.	SECTION	COUNTY	TOTAL SHEETS	SHEET NO.
4029	23-00146-00-PV	COOK	315	195
CONTRACT NO. 61M26				
ILLINOIS FED. AID PROJECT				

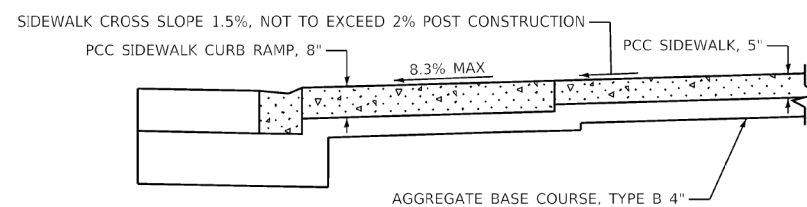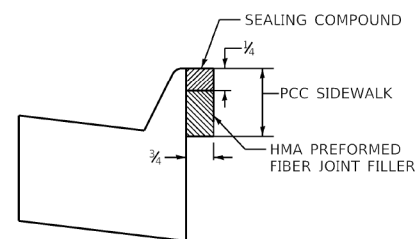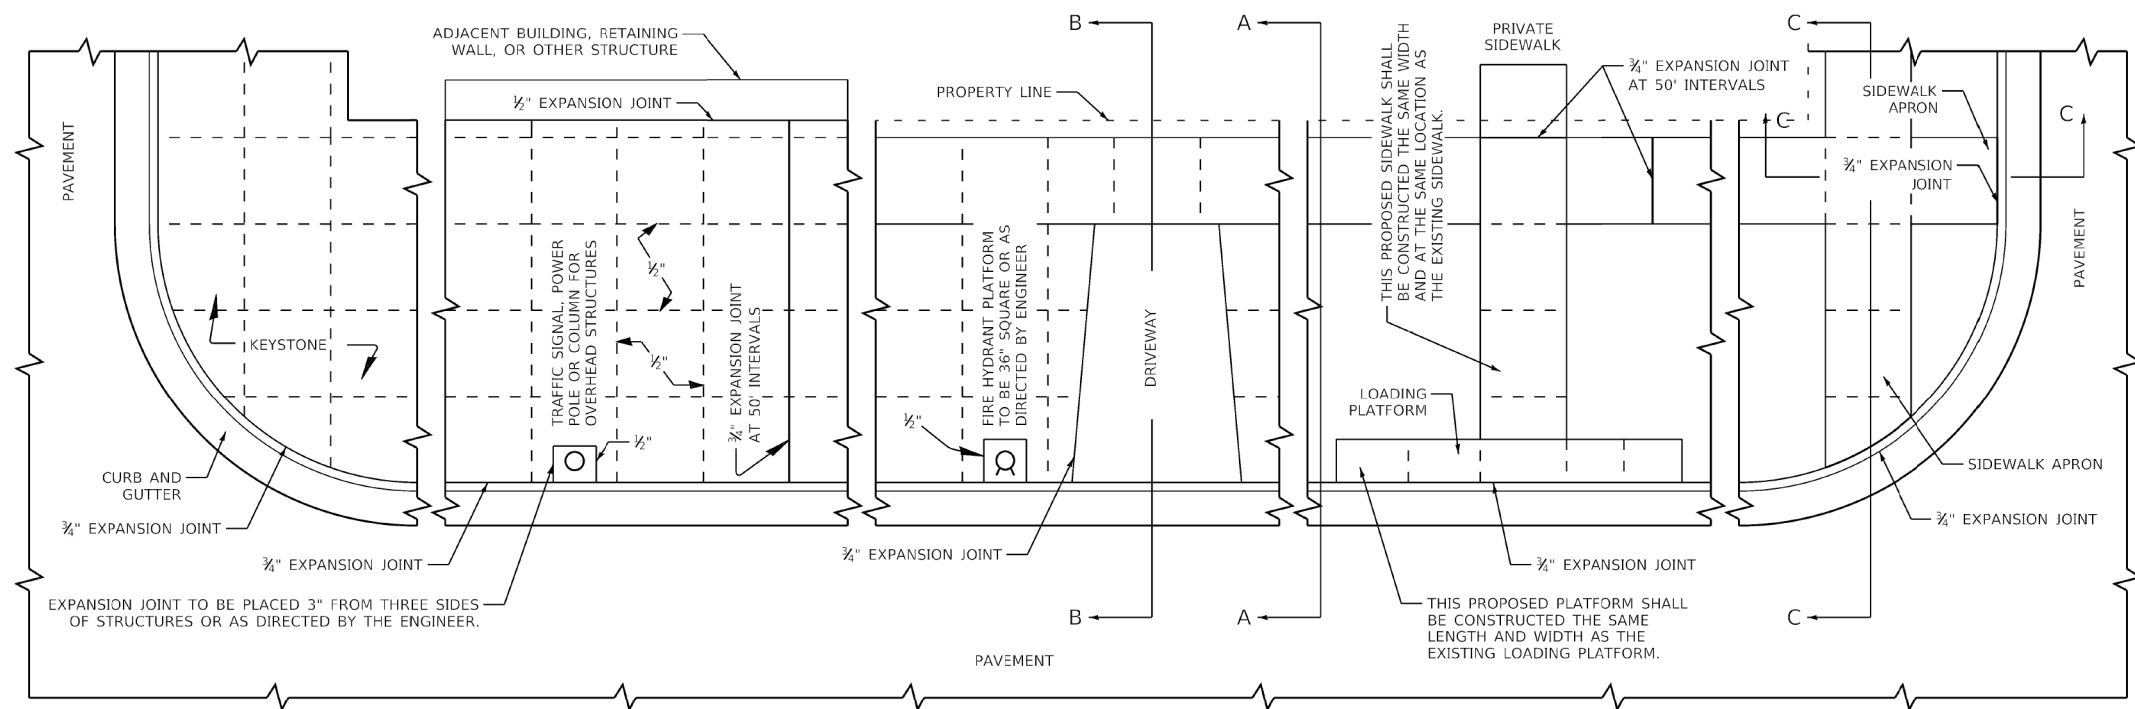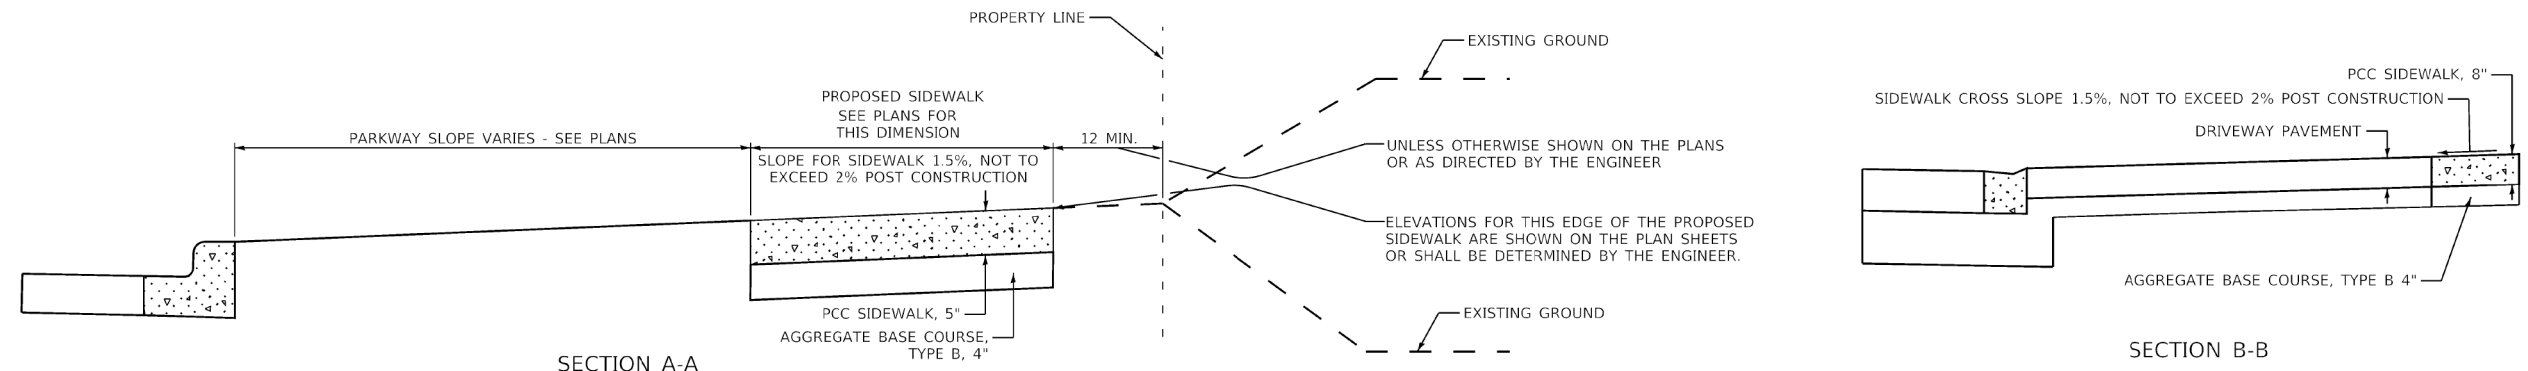

GENERAL NOTES:


ALL EXPANSION JOINTS SHALL CONFORM TO THE REQUIREMENTS OF SECTION 424.07 OF THE STANDARD SPECIFICATIONS FOR ROAD AND BRIDGE CONSTRUCTION AND SHALL BE INCLUDED IN THE CONTRACT UNIT PRICE PER SQUARE FOOT FOR PORTLAND CEMENT CONCRETE SIDEWALK OF THE THICKNESS SPECIFIED.

ALL DIMENSIONS ARE IN INCHES UNLESS OTHERWISE SHOWN.

MUNICIPALITY, IL MUNICIPALITY, IL NAME TOWNSHIP	COUNTY HIGHWAY:	XXX	 COUNTY OF COOK DEPARTMENT OF TRANSPORTATION AND HIGHWAYS	COMPUTED:	XXX	REVISIONS	DATE	PORTLAND CEMENT CONCRETE SIDEWALK CONSTRUCTION DETAIL COOK COUNTY DEPARTMENT OF TRANSPORTATION AND HIGHWAYS STANDARD C-003	C-XXX
	FISCAL YEAR:	XXXX		DRAWN:	XXX	GENERAL	1/1/20		
	SECTION:	XX-XXXX-XX-XX		CHECKED:	XXX	NEW DRAWING SECTION C-C	11/10/22		
NOT TO SCALE SHEET X									


CCDO TH SIDEWALK DETAIL (APPLICABLE ONLY IN WISE ROAD RIGHT-OF-WAY)

USER NAME = pk	DESIGNED -	REVISED -	STATE OF ILLINOIS DEPARTMENT OF TRANSPORTATION	BRAINTREE DRIVE CONSTRUCTION DETAILS				MUN/ RTE.	SECTION	COUNTY	TOTAL SHEETS	SHEET NO.
	DRAWN -	REVISED -		4029	23-00146-00-PV				COOK	315	197	
	CHECKED -	REVISED -		CONTRACT NO. 61M26								
PLOT DATE = 12/15/2025	DATE - 12/12/2025	REVISED -										
			SCALE:	SHEET 9	OF 9	SHEETS	STA.	TO STA.				
			ILLINOIS FED. AID PROJECT									

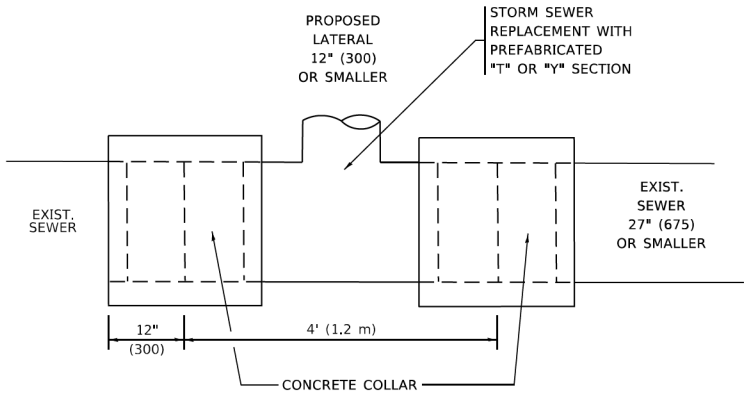


DETAIL "A"

LATERAL CONNECTION TO EXISTING SEWER
OF 27" (675) OR SMALLER

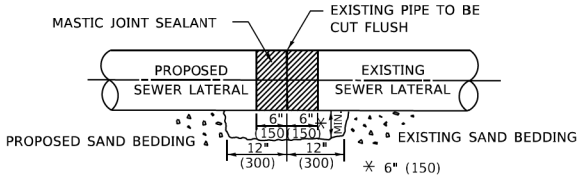

DETAIL "B"

CLASS SI CONCRETE COLLAR

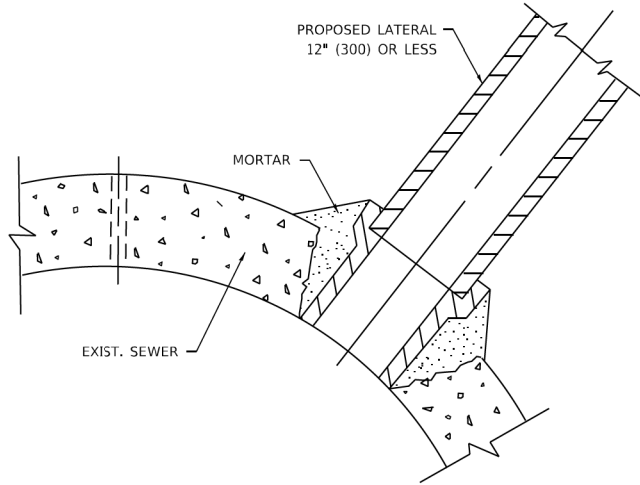

DETAIL "C"

PROPOSED LATERAL
CONNECTION TO EXISTING SEWER
OF 30" (750) OR LARGER

CONSTRUCTION SEQUENCE

1. CUT THE EXISTING END OF THE PIPE SO AS TO PRESENT A FLUSH BUTT JOINT. BRUSH AND CLEAN ALL PIPES.
2. APPLY THE MASTIC JOINT SEALANT TO THE FIRST 6" (150) OF EACH PIPE.
3. BUTT THE PIPES TOGETHER LEAVING A MINIMUM OF 12' x 6' (300 x 150) DEEP EXCAVATION UNDER AND AROUND EACH PIPE END.
4. CUT A PIECE OF SHEET METAL GAGE NO. 19 1.1 (0.0418) 18" (450) WIDE BY THE OUTSIDE CIRCUMFERANCE OF THE PIPE PLUS 3" (75) LONG.
5. WRAP THE SHEET METAL AROUND THE PIPES, 9" (225) ON EACH SIDE OF THE JOINT, STARTING AT THE TOP OF THE PIPE.
6. LAP THE SHEET METAL AT LEAST 3" (75) AT THE TOP OF THE PIPE AND PLACE THE MASTIC JOINT SEALANT BETWEEN THE LAP.
7. PLACE TWO METAL BANDS AROUND THE SHEET METAL AND TIGHTEN.
8. WIPE OFF ANY EXCESS MASTIC JOINT SEALANT THAT OOZES OUT FROM BETWEEN THE SHEET METAL AND THE PIPES.
9. PLACE CLASS SI CONCRETE AROUND THE JOINT.

NOTES:

MATERIAL

MATERIAL USED FOR THE TEE OR WYE SECTION SHALL BE COMPATIBLE WITH THE EXISTING STORM SEWER OR THE PROPOSED STORM SEWER.

CONSTRUCTION METHODS

- I. THIS WORK SHALL BE CONSTRUCTED IN CONFORMANCE WITH THE APPLICABLE PORTIONS OF SECTION 550 OF THE STANDARD SPECIFICATIONS.
- II. CONNECTION TO AN EXISTING STORM SEWER SHALL BE BY EITHER OF THE FOLLOWING METHODS:
 - A) PROPOSED STORM SEWER CONNECTION TO EXISTING SEWER OF 27" (675) OR SMALLER SEE DETAIL "A" AND "B".
 - B) PROPOSED STORM SEWER CONNECTION TO EXISTING SEWER OF 30" (750) OR LARGER SEE DETAIL "C".

IF THE EXISTING SEWER PIPE IS CRACKED, BROKEN OR OTHERWISE DAMAGED BY THE CONTRACTOR IN MAKING THE CIRCULAR OPENING, THE CONTRACTOR SHALL REPLACE THAT SECTION OF PIPE WITH PIPE EQUAL AND SIMILAR IN ALL RESPECTS TO THE PIPE IN THE EXISTING SEWER, IN A CAREFUL WORKMANLIKE MANNER, WITHOUT EXTRA COMPENSATION.

GENERAL

1. CARE MUST BE TAKEN TO PREVENT DEBRIS FROM ENTERING THE SEWER. ALL DEBRIS WHICH ENTERS THE SEWER MUST BE REMOVED. THE SEWER MUST BE LEFT CLEAN AND UNOBSTRUCTED UPON COMPLETION OF THE CONTRACT.
2. CARE MUST BE TAKEN TO PREVENT ANY PART OF THE NEW PIPE CONNECTION FROM PROJECTING INTO THE EXISTING SEWER.

BASIS OF PAYMENT


1. TEE OR WYE CONNECTIONS SHALL BE PAID FOR AT THE CONTRACT UNIT PRICE EACH FOR STORM SEWER TEE OR WYE OF THE TYPE AND SIZE SPECIFIED IN THE PLANS, THIS PRICE SHALL INCLUDE ALL EXCAVATION OF THE TRENCH, REMOVAL OF THE EXISTING STORM SEWER, FURNISHING AND INSTALLING THE SPECIFIED TEE OR WYE SECTION, FURNISHING AND INSTALLING THE REQUIRED CONCRETE COLLAR, AND ALL OTHER MATERIAL NECESSARY TO COMPLETE THIS WORK AS SHOWN AND SPECIFIED.
2. REMOVAL AND REINSTALLATION OF EXISTING STORM SEWER ADJACENT TO THE PROPOSED TEE OR WYE SECTION, FOR THE PURPOSE OF FACILITATING THE INSTALLATION OF THE TEE OR WYE SECTION, WILL NOT BE PAID FOR SEPARATELY BUT SHALL BE INCLUDED IN THE UNIT PRICE BID FOR THE WORK.
3. TRENCH BACKFILL, EXCAVATION IN ROCK AND REMOVAL AND REPLACEMENT OF UNSUITABLE MATERIAL BELOW PLAN BEDDING GRADE WILL BE PAID FOR SEPARATELY.
4. CONCRETE COLLAR FOR CONNECTING A PROPOSED STORM SEWER TO AN EXISTING STORM SEWER WILL NOT BE PAID FOR SEPARATELY BUT SHALL BE INCLUDED IN THE COST OF THE PROPOSED STORM SEWER.

* ALL DIMENSIONS ARE IN INCHES (MILLIMETERS)
UNLESS OTHERWISE SHOWN.

MODEL: Default
FILE: \\nrc-srv-bentley.com\PI\PIDOT\Documents\DOT_Offices\District 1\Projects\Dis422\23\ACAD\DetailCAD\Sheet1b.dgn

MODEL: Default
FILE NAME: DWG

	USER NAME = Lawrence,DeManche	DESIGNED - M. DE YONG	REVISED - R. SHAH 09-09-94	STATE OF ILLINOIS DEPARTMENT OF TRANSPORTATION	DETAIL OF STORM SEWER CONNECTION TO EXISTING SEWER					MUN RTE.	SECTION	COUNTY	TOTAL SHEETS	SHEET NO.			
		DRAWN -	REVISED - R. SHAH 10-25-94							4029	23-00146-00-PV	COOK	315	198			
	PLOT SCALE = 100.0000 ' / in.	CHECKED -	REVISED - R. SHAH 06-12-96							BD500-01 (BD-07)					CONTRACT NO.61M26		
	PLOT DATE = 11/18/2022	DATE - 07-25-90	REVISED - K. SMITH 11-18-22							ILLINOIS FED. AID PROJECT							
	SCALE: NONE									SHEET 1	OF 1	SHEETS	STA.	TO STA.			

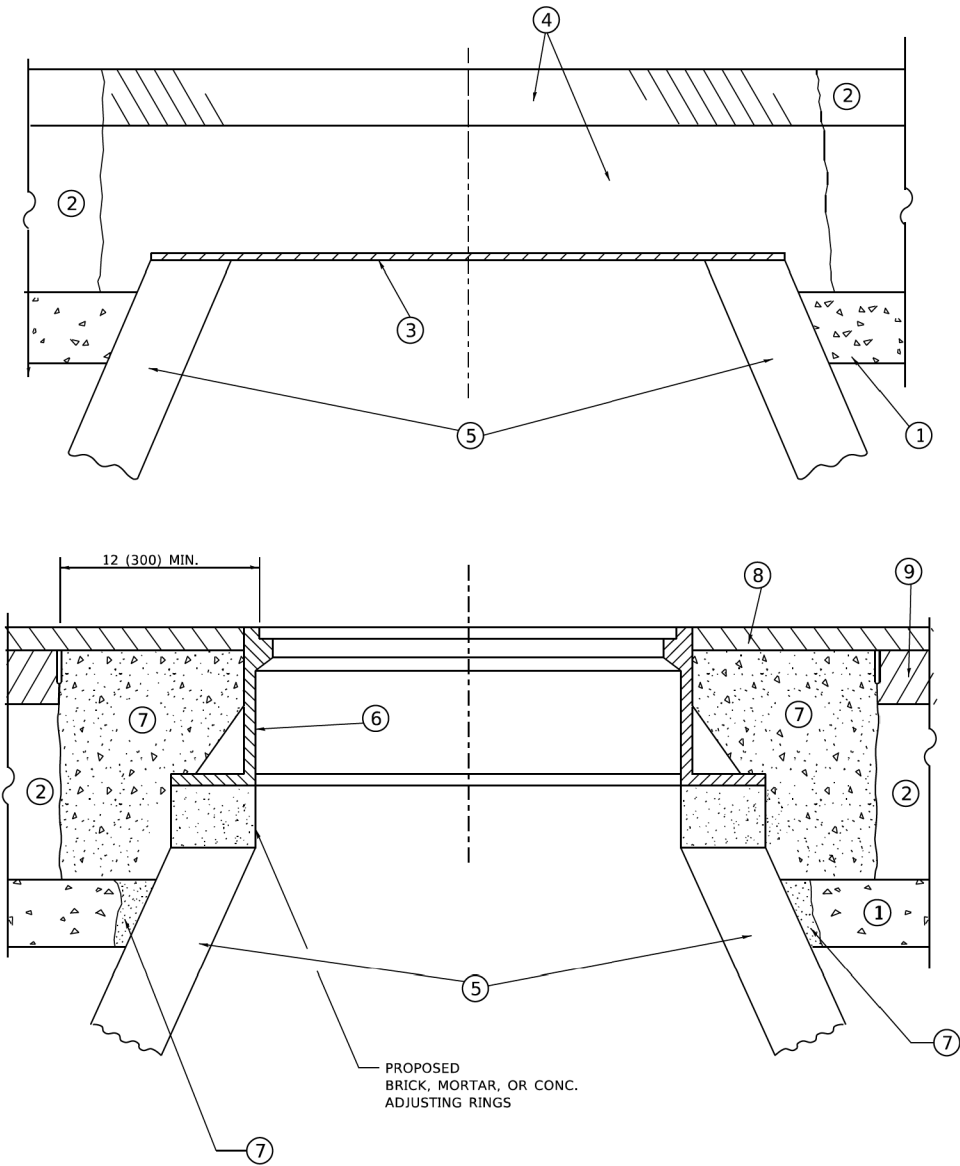

**DETAILS FOR FRAMES AND LIDS ADJUSTMENT
WITH MILLING**

NOTES

- EXISTING BROKEN FRAMES AND LIDS SHALL BE REMOVED AND DISPOSED OF BY THE CONTRACTOR AND SHALL BE REPLACED AS DIRECTED BY THE ENGINEER. REPLACEMENT FRAMES AND LIDS WILL BE PAID FOR IN ACCORDANCE WITH ARTICLE 109.04 OF THE STANDARD SPECIFICATIONS UNLESS A SEPARATE PAY ITEM HAS BEEN PROVIDED.
- IF THE EXISTING LIDS ARE OPEN, THE FRAME WILL BE ADJUSTED TO THE ELEVATION OF THE MILLED PAVEMENT SURFACE PRIOR TO THE MILLING OPERATION. THE FRAME WILL NOT BE REMOVED AND COVERED BY THE METAL PLATE.
- CITY OF CHICAGO CASTINGS ARE THE PROPERTY OF THE CITY AND THE CONTRACTOR SHALL NOTIFY THE CITY FOR REMOVAL AND DISPOSITION OF THE CASTINGS.
- THE METAL PLATE USED TO COVER THE STRUCTURE SHALL REMAIN THE PROPERTY OF THE CONTRACTOR.
- THE CONTRACTOR SHALL REMOVE ALL TRAFFIC CONTROL DEVICES BY THE END OF EACH WORK SHIFT.

CONSTRUCTION PROCEDURES

STAGE 1 (BEFORE PAVEMENT MILLING)

- REMOVE A MINIMUM OF 12 (300) OF THE PAVEMENT FROM AROUND THE STRUCTURE.
- REMOVE THE EXISTING FRAME AND LID FROM THE STRUCTURE.
- COVER THE STRUCTURE OPENING WITH A 36 (900) DIAMETER METAL PLATE.
- BACKFILL WITH CRUSHED STONE AND HMA SURFACE MIX APPROVED BY THE ENGINEER. (MIN. 3 (80) HMA TO REMAIN AFTER MILLING).

STAGE 2 (AFTER PAVEMENT MILLING)

- REMOVE THE HMA SURFACE MIX AND CRUSHED STONE.
- INSTALL THE FRAME AND LID; ADJUST THE FRAME TO ITS FINAL SURFACE ELEVATION.
- THE SURROUNDING SPACE SHALL BE FILLED WITH CLASS PP-2* CONCRETE TO THE ELEVATION OF THE SURFACE OF THE EXISTING BASE COURSE OR THE BINDER COURSE.

* UNLESS OTHERWISE SPECIFIED IN THE PLANS.

THE PROCEDURE EXPLAINED ABOVE SHALL CONFORM TO THE APPLICABLE PORTIONS OF SECTIONS 353, 406, 602, AND 603 OF THE STANDARD SPECIFICATIONS EXCEPT THAT "THE CONTRACTOR SHALL ADJUST THE STRUCTURES TO THE FINISHED PAVEMENT ELEVATION NO MORE THAN 5 CALENDAR DAYS PRIOR TO PLACEMENT OF THE FINAL LIFT OF SURFACE UNLESS APPROVED BY THE ENGINEER."

LEGEND

- | | |
|--|-------------------------------|
| ① SUB-BASE GRANULAR MATERIAL | ⑥ FRAME AND LID (SEE NOTES) |
| ② EXISTING PAVEMENT | ⑦ CLASS PP-2* CONCRETE |
| ③ 36 (900) DIAMETER METAL PLATE | ⑧ PROPOSED HMA SURFACE COURSE |
| ④ PROPOSED CRUSHED STONE AND HMA SURFACE MIX | ⑨ PROPOSED HMA BINDER COURSE |
| ⑤ EXISTING STRUCTURE | |

LOCATION OF STRUCTURES

THE CONTRACTOR WILL BE REQUIRED TO KEEP A RECORD OF THE LOCATIONS OF THE BURIED STRUCTURES ACCORDING TO THE STATION AND DISTANCE LEFT OR RIGHT OF THE CENTERLINE OF PAVEMENT. UPON COMPLETION OF THE WORK, THE CONTRACTOR WILL DELIVER THE RECORD TO THE ENGINEER.

BASIS OF PAYMENT

- REMOVING FRAMES AND LIDS ON DRAINAGE AND UTILITY STRUCTURES IN THE PAVEMENT PRIOR TO MILLING, AND ADJUSTING TO FINAL GRADE PRIOR TO PLACING THE SURFACE COURSE, WILL BE PAID FOR AT THE CONTRACT UNIT PRICE EACH FOR "FRAMES AND LIDS TO BE ADJUSTED (SPECIAL)."
- THIS WORK WILL NOT BE PAID FOR WHEN DRAINAGE AND UTILITY STRUCTURES ARE SPECIFIED FOR PAYMENT AS STRUCTURE RECONSTRUCTION.
- NEW FRAMES AND LIDS, WHEN SPECIFIED, WILL BE PAID FOR SEPARATELY.
- WHEN STRUCTURES ARE TO BE ADJUSTED OR RECONSTRUCTED, THE LOWERING AND RAISING OF THE FRAMES AND LIDS WILL NOT BE PAID FOR SEPARATELY BUT WILL BE INCLUDED IN THE COST OF THE CORRESPONDING PAY ITEM.

ALL DIMENSIONS ARE IN INCHES (MILLIMETERS) UNLESS OTHERWISE SHOWN

MODEL Default
FILE Name: W:\detroit\22-34\bd08.dgn


USER NAME = Lawrence,DeManche	DESIGNED - R. SHAH	REVISED - R. BORO 03-09-11
	DRAWN -	REVISED - R. BORO 12-06-11
PLOT SCALE = 100.0000 ' / in.	CHECKED -	REVISED - K. SMITH 11-18-22
PLOT DATE = 9/15/2023	DATE - 10-25-94	REVISED - K. SMITH 09-15-23

**STATE OF ILLINOIS
DEPARTMENT OF TRANSPORTATION**

**DETAILS FOR
FRAMES AND LIDS ADJUSTMENT WITH MILLING**


SCALE: NONE SHEET 1 OF 1 SHEETS STA. TO STA.

MUN RTE.	SECTION	COUNTY	TOTAL SHEETS	SHEET NO.
4029	23-00146-00-PV	COOK	315	199
BD600-03 (BD-08)		CONTRACT NO.61M26		
		ILLINOIS FED. AID PROJECT		

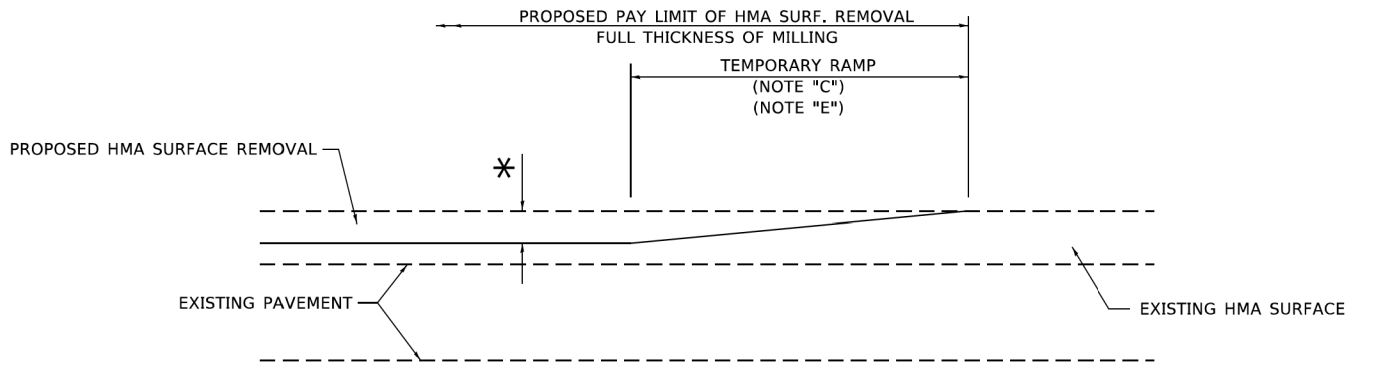

MILLED TEMPORARY RAMP
(FOR BUTT JOINT AND HMA TAPER SEE DETAIL BELOW)


OPTION 1

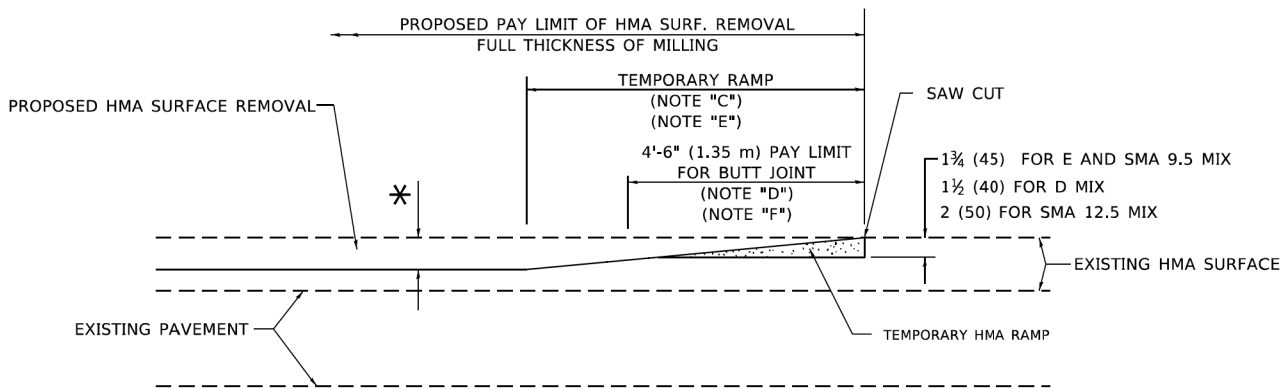

HMA CONSTRUCTED TEMPORARY RAMP
(FOR BUTT JOINT AND HMA TAPER SEE DETAIL BELOW)


OPTION 2

TYPICAL TEMPORARY RAMP

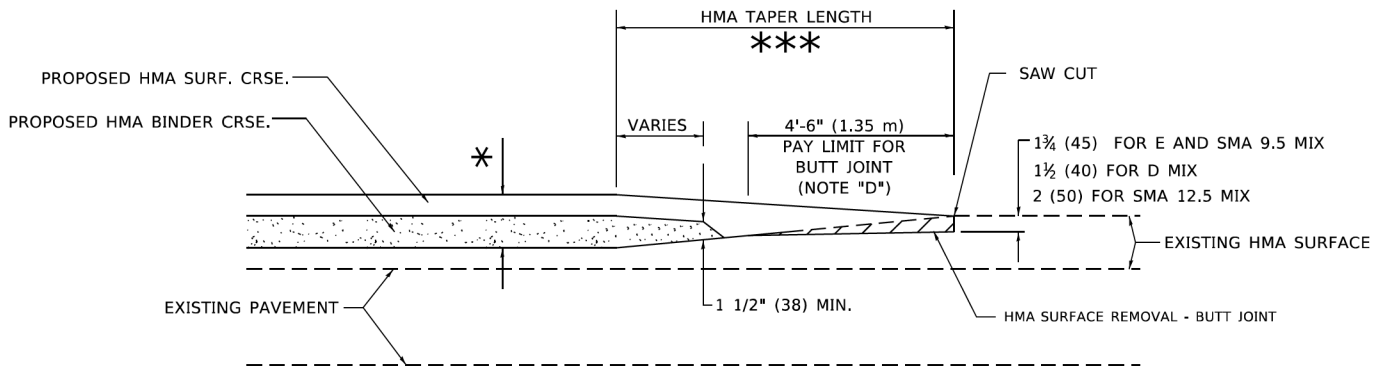


BUTT JOINT AND
HMA TAPER

TYPICAL BUTT JOINT AND HMA TAPER
FOR MILLING AND RESURFACING

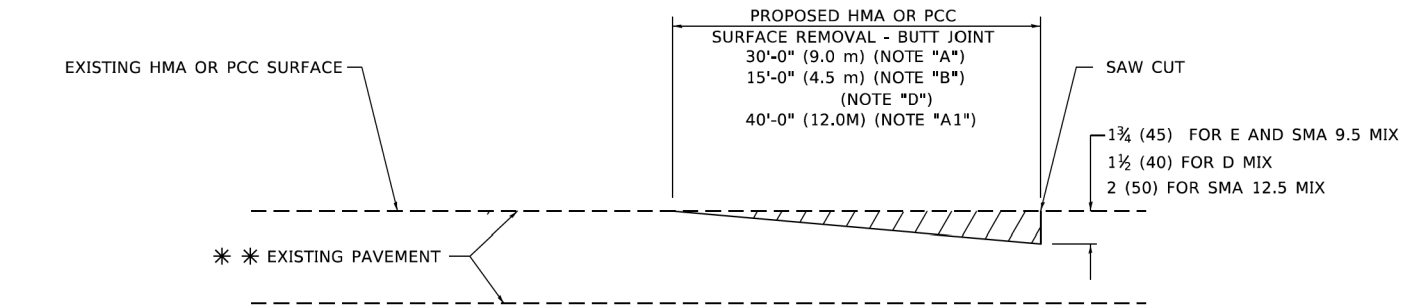

BUTT JOINT DETAIL

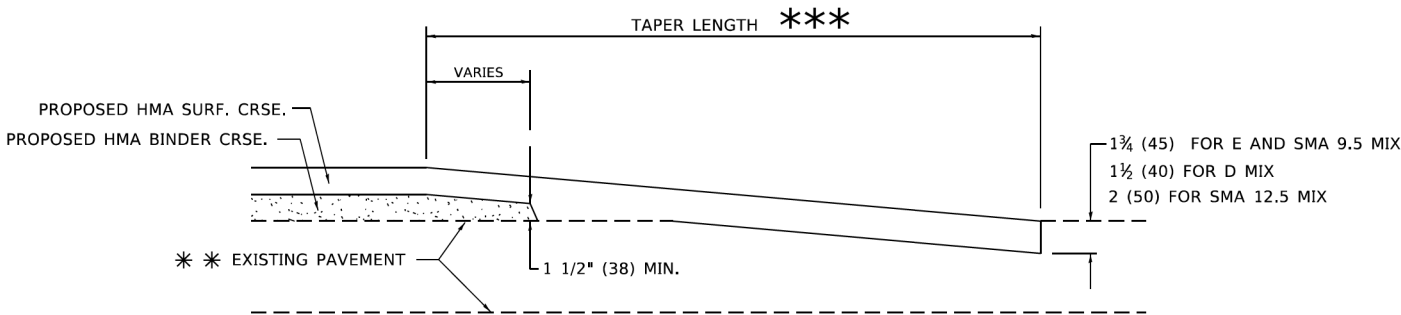

HMA TAPER DETAIL

TYPICAL BUTT JOINT AND HMA TAPER
FOR RESURFACING ONLY

** PC CONCRETE, HMA OR HMA RESURFACED PAVEMENT.

GENERAL NOTES

- A. MAINLINE ARTERIAL ROADWAYS AND MAJOR SIDE ROADS.
- A1. INTERSTATES
- B. MINOR SIDE ROADS.
- C. THE TEMP. RAMP SHALL BE CONSTRUCTED IMMEDIATELY UPON REMOVAL OF THE EXISTING HMA SURFACE.
- D. THE BUTT JOINT SHALL BE CONSTRUCTED IMMEDIATELY PRIOR TO PLACING THE PROPOSED HMA COURSES.
- E. TAPER THE TEMP. RAMP AT A RATE OF 3' - 4" (1.02m) PER 1 INCH (25 mm) OF MILLING THICKNESS.
* SEE TYPICAL SECTIONS FOR MILLING THICKNESS.
- F. SEE ARTICLE 406.08 AND 406.14 OF THE STANDARD SPECIFICATIONS FOR "HMA AND/OR PCC SURFACE REMOVAL, BUTT JOINT".
*** 20'-0" (6.1 m) PER 1 (25) RESURFACING (NOTE "A")
10'-0" (3.0 m) PER 1 (25) RESURFACING (NOTE "B")

BASIS OF PAYMENT

- 1. THE BUTT JOINT WILL BE PAID FOR AT THE CONTRACT UNIT PRICE PER SQUARE YARD (SQUARE METER) FOR "HOT-MIX ASPHALT SURFACE REMOVAL - BUTT JOINT" OR FOR "PORTLAND CEMENT CONCRETE SURFACE REMOVAL- BUTT JOINT".
- 2. THE TEMPORARY RAMP AND SAW CUT SHALL BE INCLUDED IN THE UNIT COST FOR HMA OR PCC SURFACE REMOVAL-BUTT JOINT.

ALL DIMENSIONS ARE IN INCHES (MILLIMETERS) UNLESS OTHERWISE SHOWN.

MODEL: Default
FILE: hma12.ctb
C:\Users\jlawrence\OneDrive\Documents\DOT Office\District 1\Projects\District 1\Projects\District 1\ACAD\Drawings\CD\Sheet\bd32.dgn

USER NAME = Lawrence,DeManche	DESIGNED - M. DE YONG	REVISED - A. ABBAS 03-21-97
	DRAWN -	REVISED - M. GOMEZ 04-06-01
PLOT SCALE = 100.0000 ' / in.	CHECKED -	REVISED - R. BORO 01-01-07
PLOT DATE = 11/18/2022	DATE - 06-13-90	REVISED - K. SMITH 11-18-22

STATE OF ILLINOIS
DEPARTMENT OF TRANSPORTATION

BUTT JOINT AND
HMA TAPER DETAILS

SCALE: NONE SHEET 1 OF 1 SHEETS STA. TO STA.

MUN RTE.	SECTION	COUNTY	TOTAL SHEETS	SHEET NO.
4029	23-00146-00-PV	COOK	315	200
BD400-05 BD-32		CONTRACT NO.61M26		
ILLINOIS		FED. AID PROJECT		