


MODEL: Default
FILE: \\kimley-horn-bentley.com\khp\p4\1\Documents\01 Active Projects\MIW\CHS-16895\100 - IL 64\Phase II\2 Design\CAD\Plan Sheets\Roadway\1\08121-shr-pmk-20_KHA.dgn

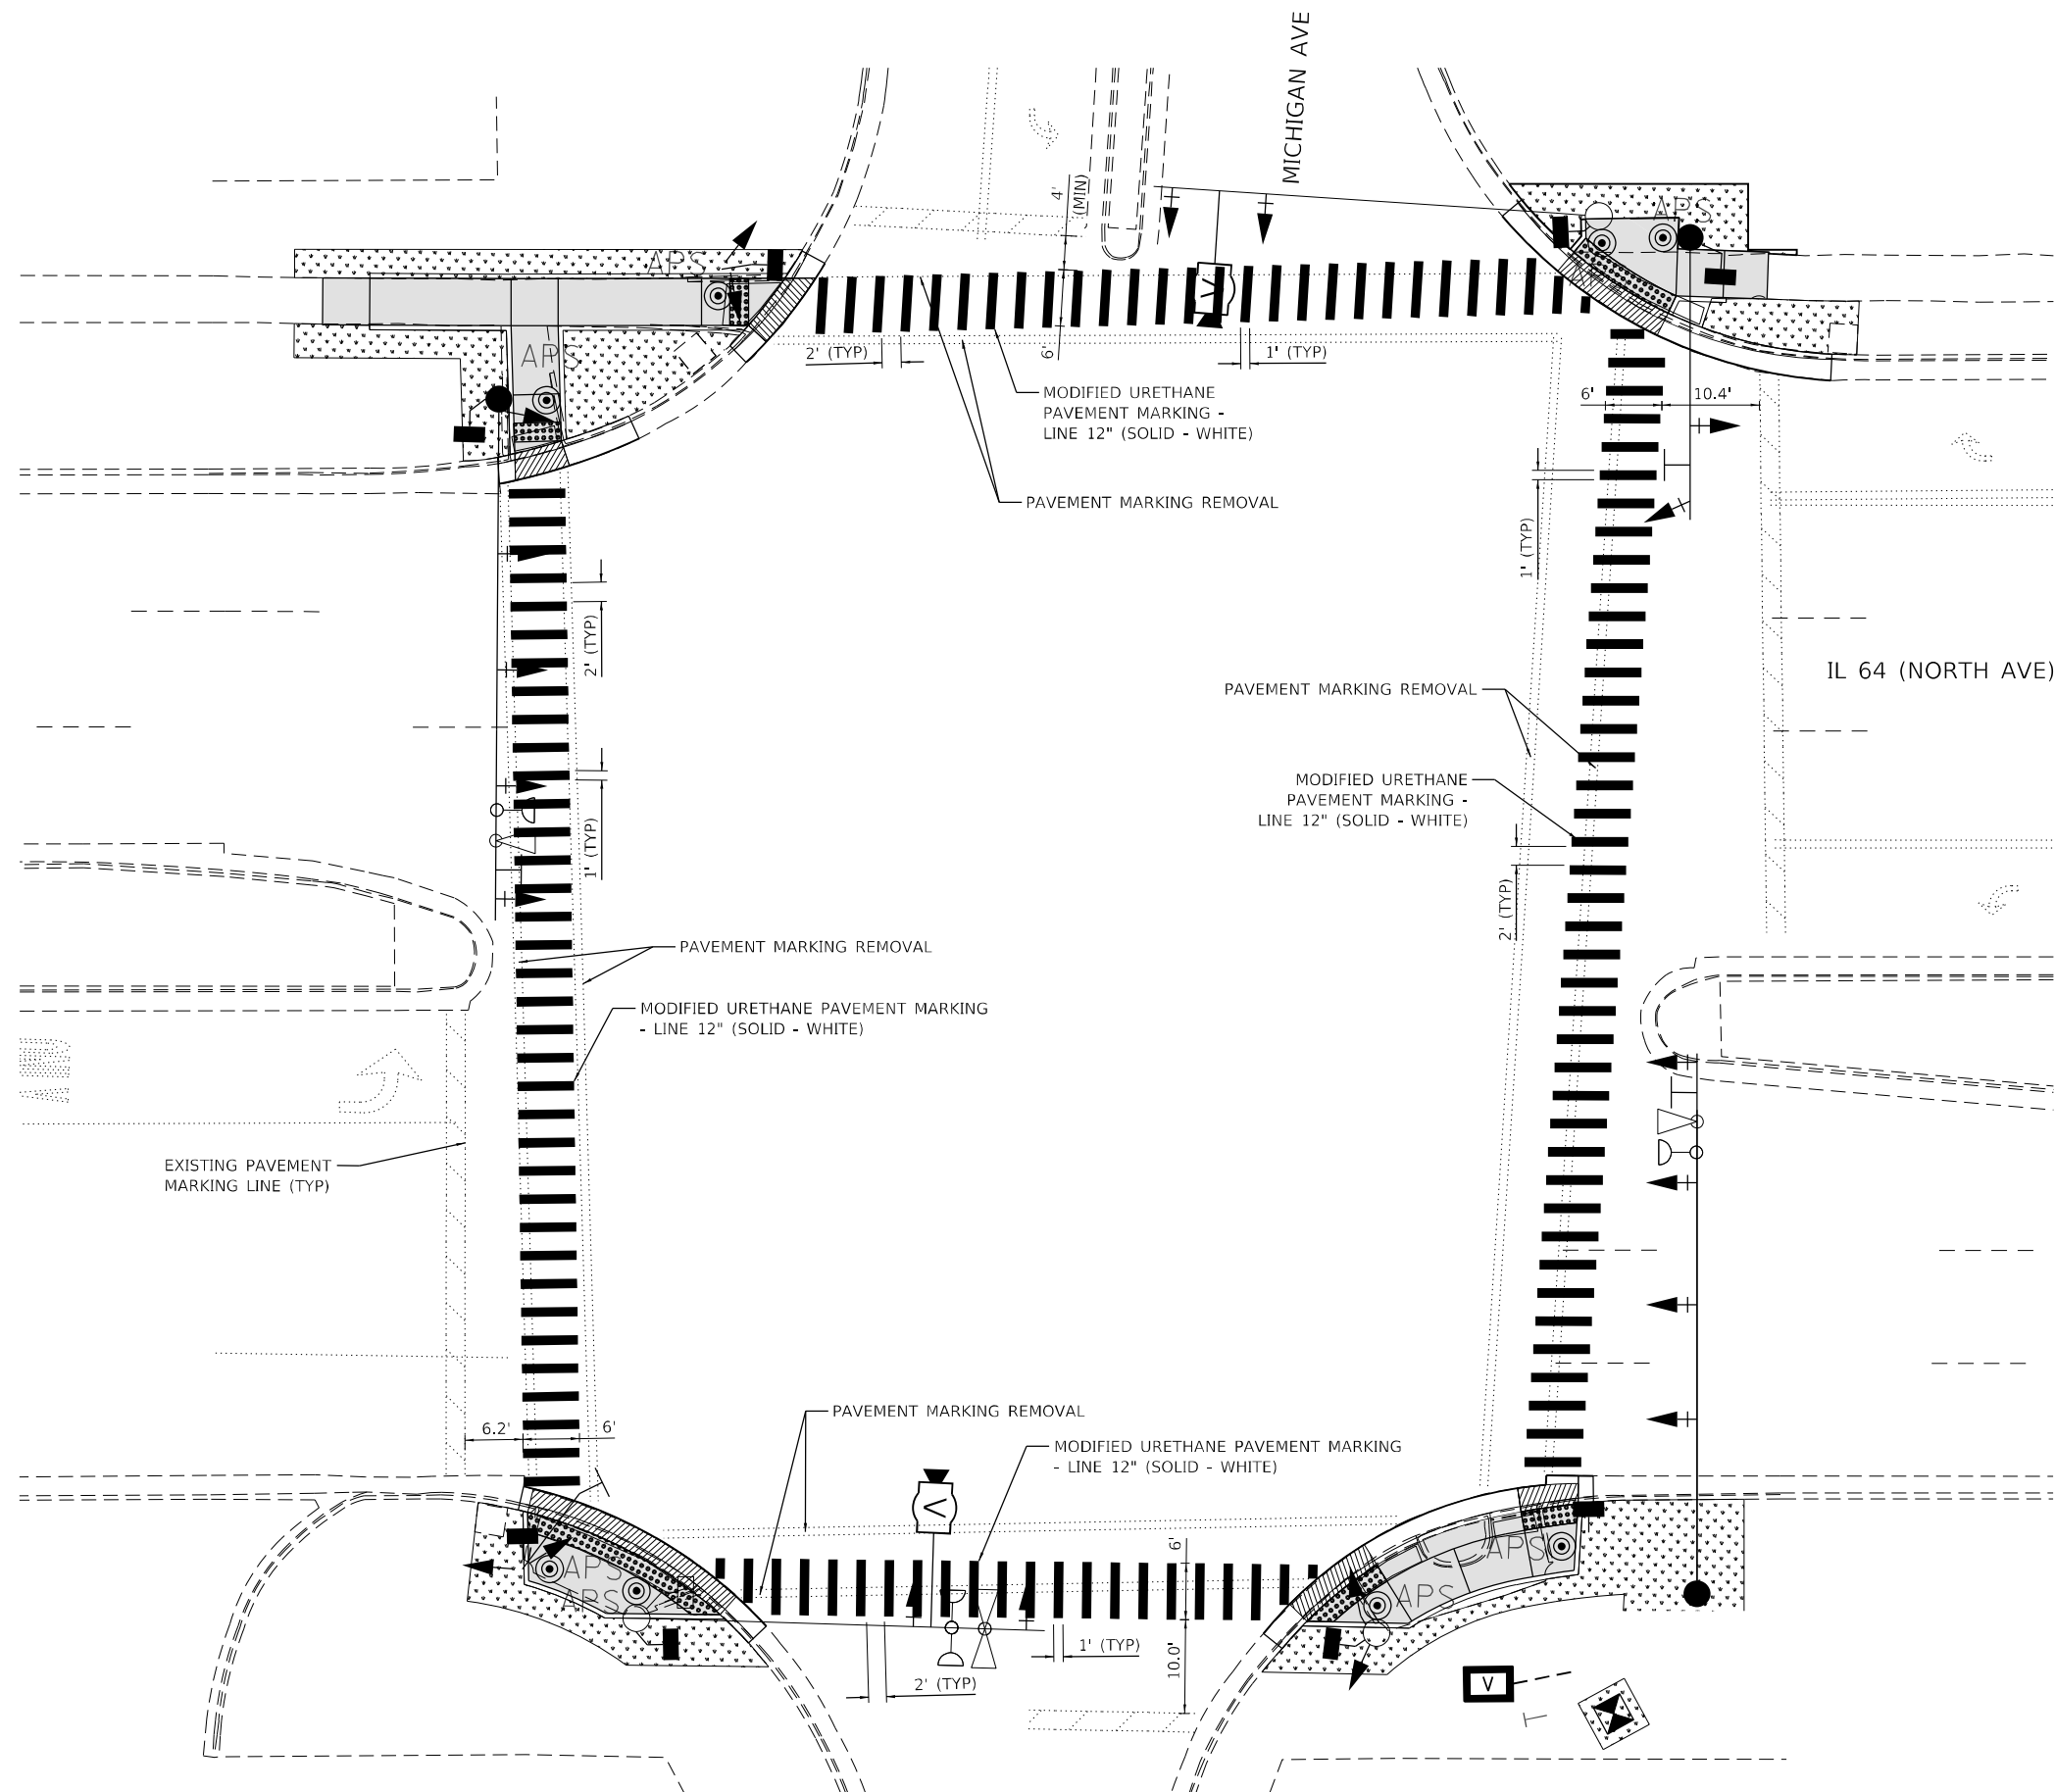



USER NAME =	DESIGNED -	REVISED -
	DRAWN -	REVISED -
PLOT SCALE =	CHECKED -	REVISED -
PLOT DATE =	DATE -	REVISED -

STATE OF ILLINOIS
DEPARTMENT OF TRANSPORTATION

PAVEMENT MARKING PLAN			
IL 64 (NORTH AVE) AND MICHIGAN AVE			
SCALE: 1" = 10'	SHEET	OF	SHEETS
	STA.	TO	STA.

F.A.P. RTE.	SECTION	COUNTY	TOTAL SHEETS	SHEET NO.
307	2020-263-SUR, SW&TS	DUPAGE	529	101
CONTRACT NO. 62N33				
ILLINOIS FED. AID PROJECT				

MODEL: Default
FILE: \\state-prod\hwy-bentley.com\k-h-pw-d\Documents\01 Active Projects\WW-CUS-160950-100 - IL 64\Phase II\2 Design\CAO\Plan Sheets\Roadway\0108121-shr-PMK-21_KHA.dgn

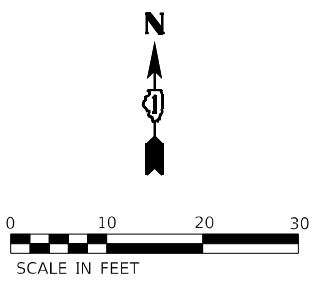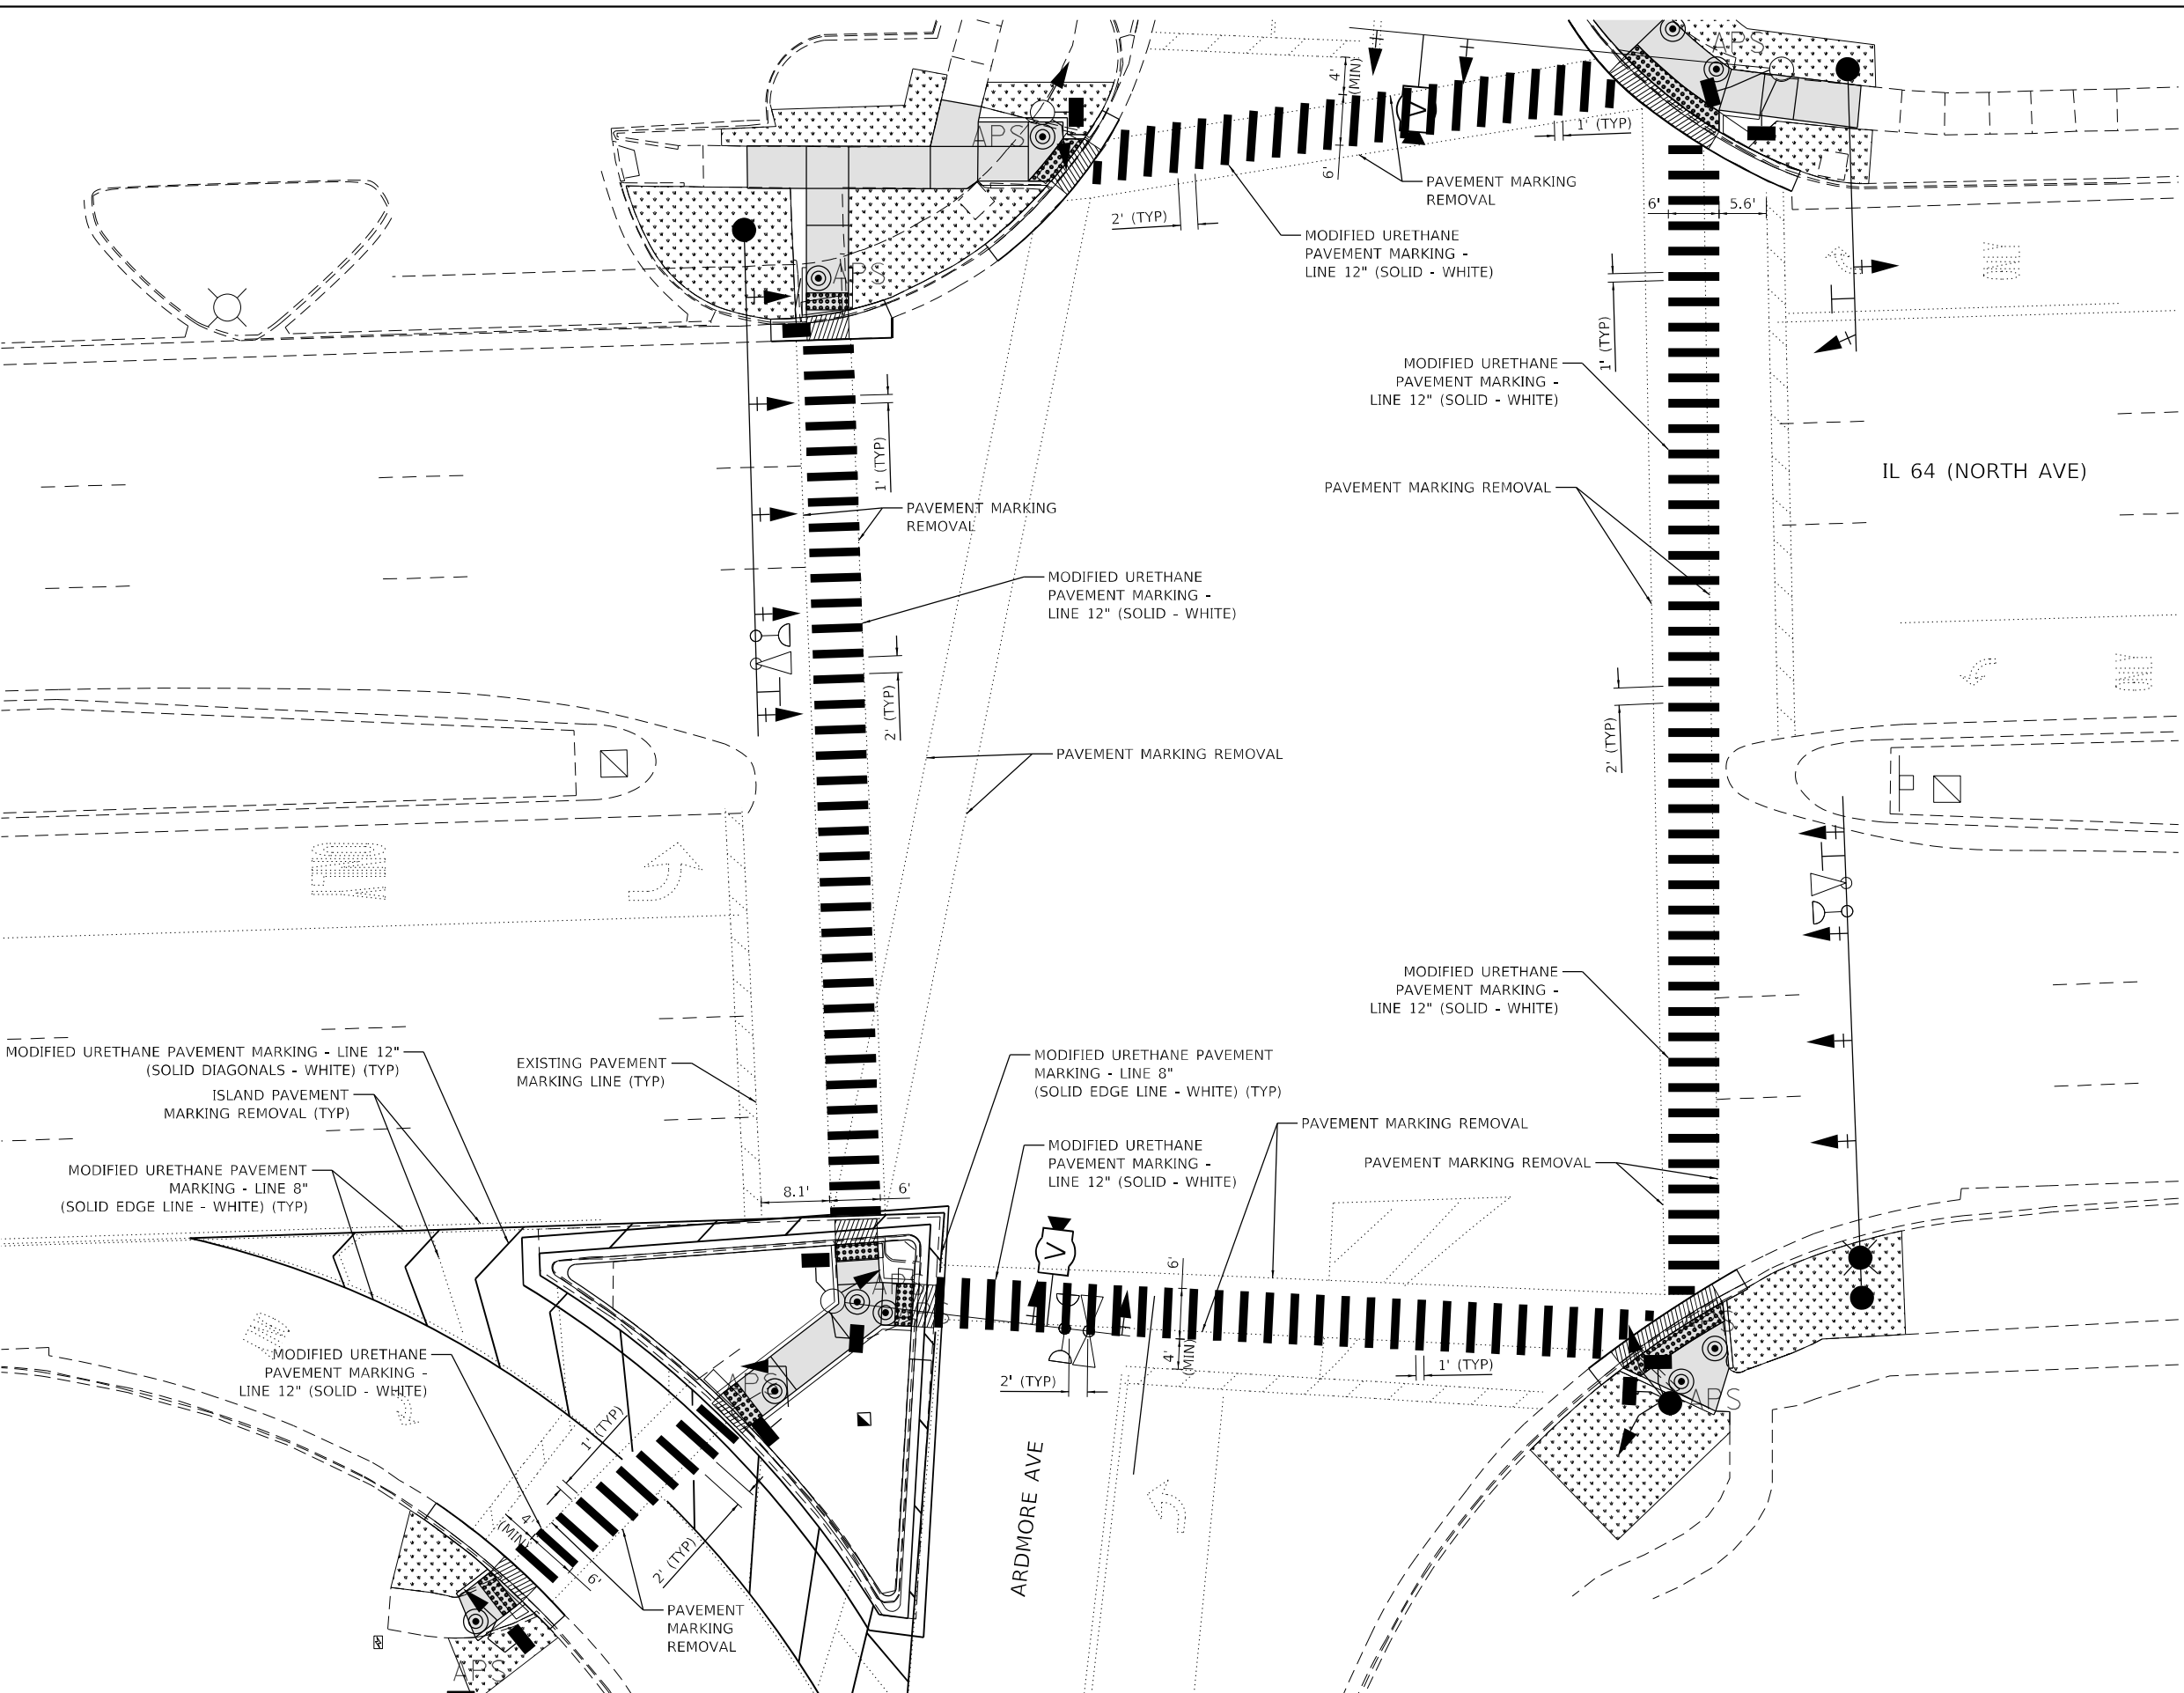

Kimley»Horn
© 2023 KIMLEY-HORN AND ASSOCIATES, INC.
4001 WILLOW ROAD, SUITE 400
WARREN, IL 60595
PHONE: (847) 460-4600
WWW.KIMLEY-HORN.COM

USER NAME =	DESIGNED -	REVISED -
	DRAWN -	REVISED -
PLOT SCALE =	CHECKED -	REVISED -
PLOT DATE =	DATE -	REVISED -


**STATE OF ILLINOIS
DEPARTMENT OF TRANSPORTATION**

**PAVEMENT MARKING PLAN
IL 64 (NORTH AVE) AND ARDMORE AVE**

SCALE: 1" = 10' SHEET OF SHEETS STA. TO STA.

F.A.P. RTE.	SECTION	COUNTY	TOTAL SHEETS	SHEET NO.
307	2020-263-SUR, SW&TS	DUPAGE	529	102
CONTRACT NO. 62N33				
ILLINOIS FED. AID PROJECT				

MODEL: Default
FILE: \\kimley-horn-bentley.com\khp\p4\11\Documents\01 Active Projects\IMW\CHS-168959\00 - IL 64\Phase 1\12 Design\CAD\Plan_Sheets\Signal\West Corridor_Signals\01081714-14-14-01_KIM.dgn

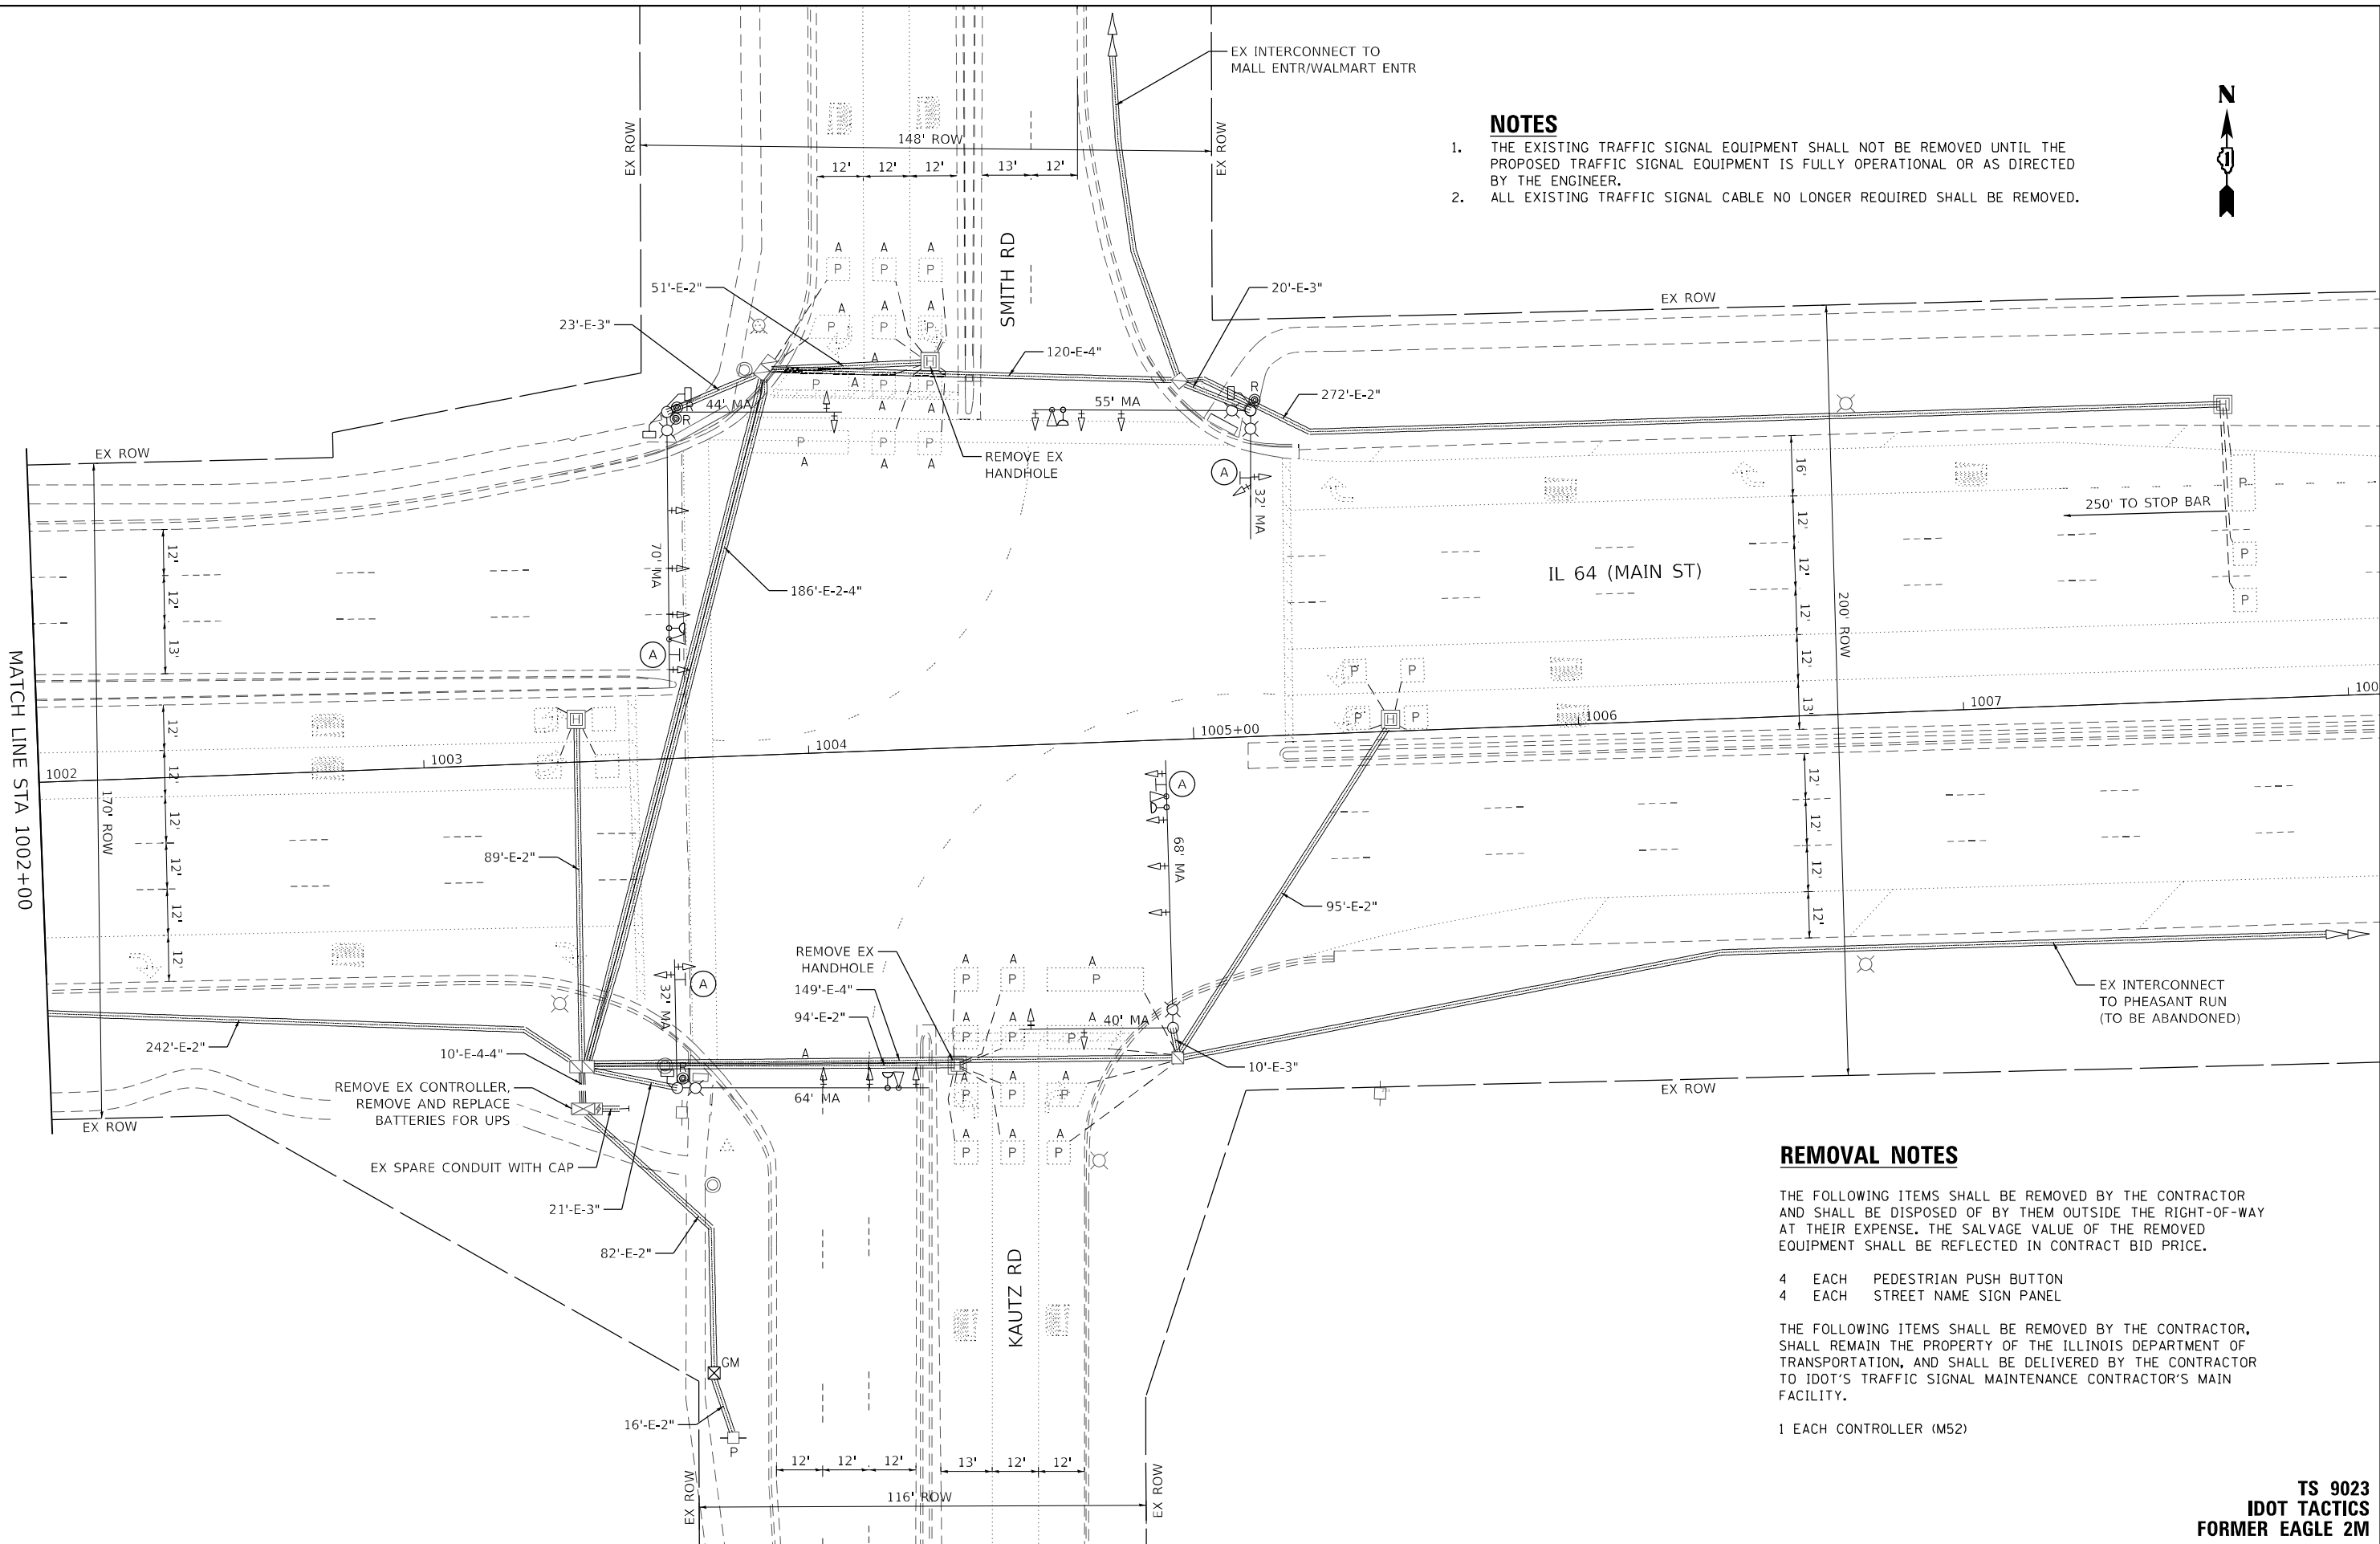

NOTES

1. THE EXISTING TRAFFIC SIGNAL EQUIPMENT SHALL NOT BE REMOVED UNTIL THE PROPOSED TRAFFIC SIGNAL EQUIPMENT IS FULLY OPERATIONAL OR AS DIRECTED BY THE ENGINEER.
2. ALL EXISTING TRAFFIC SIGNAL CABLE NO LONGER REQUIRED SHALL BE REMOVED.



REMOVAL NOTES

THE FOLLOWING ITEMS SHALL BE REMOVED BY THE CONTRACTOR AND SHALL BE DISPOSED OF BY THEM OUTSIDE THE RIGHT-OF-WAY AT THEIR EXPENSE. THE SALVAGE VALUE OF THE REMOVED EQUIPMENT SHALL BE REFLECTED IN CONTRACT BID PRICE.



- 4 EACH PEDESTRIAN PUSH BUTTON
- 4 EACH STREET NAME SIGN PANEL

THE FOLLOWING ITEMS SHALL BE REMOVED BY THE CONTRACTOR, SHALL REMAIN THE PROPERTY OF THE ILLINOIS DEPARTMENT OF TRANSPORTATION, AND SHALL BE DELIVERED BY THE CONTRACTOR TO IDOT'S TRAFFIC SIGNAL MAINTENANCE CONTRACTOR'S MAIN FACILITY.

- 1 EACH CONTROLLER (M52)

TS 9023
IDOT TACTICS
FORMER EAGLE 2M

Kimley»Horn © 2023 KIMLEY-HORN AND ASSOCIATES, INC. 4001 WILHELM ROAD, SUITE 600 WARREN, ILL. 60555 PHONE: 630-447-6050 WWW.KIMLEY-HORN.COM	USER NAME	=		DESIGNED	-		REVISED	-		STATE OF ILLINOIS DEPARTMENT OF TRANSPORTATION	TRAFFIC SIGNAL EQUIPMENT REMOVAL PLAN IL 64 (MAIN ST) AND SMITH RD/KAUTZ RD				F.A.P. RTE.	SECTION	COUNTY	TOTAL SHEETS	SHEET NO.		
	PLOT SCALE	=		CHECKED	-		REVISED	-				SCALE: 1" = 20'	SHEET	OF	SHEETS	STA.	TO STA.	CONTRACT NO. 62N33			
	PLOT DATE	=		DATE	-		REVISED	-										ILLINOIS	FED. AID PROJECT		

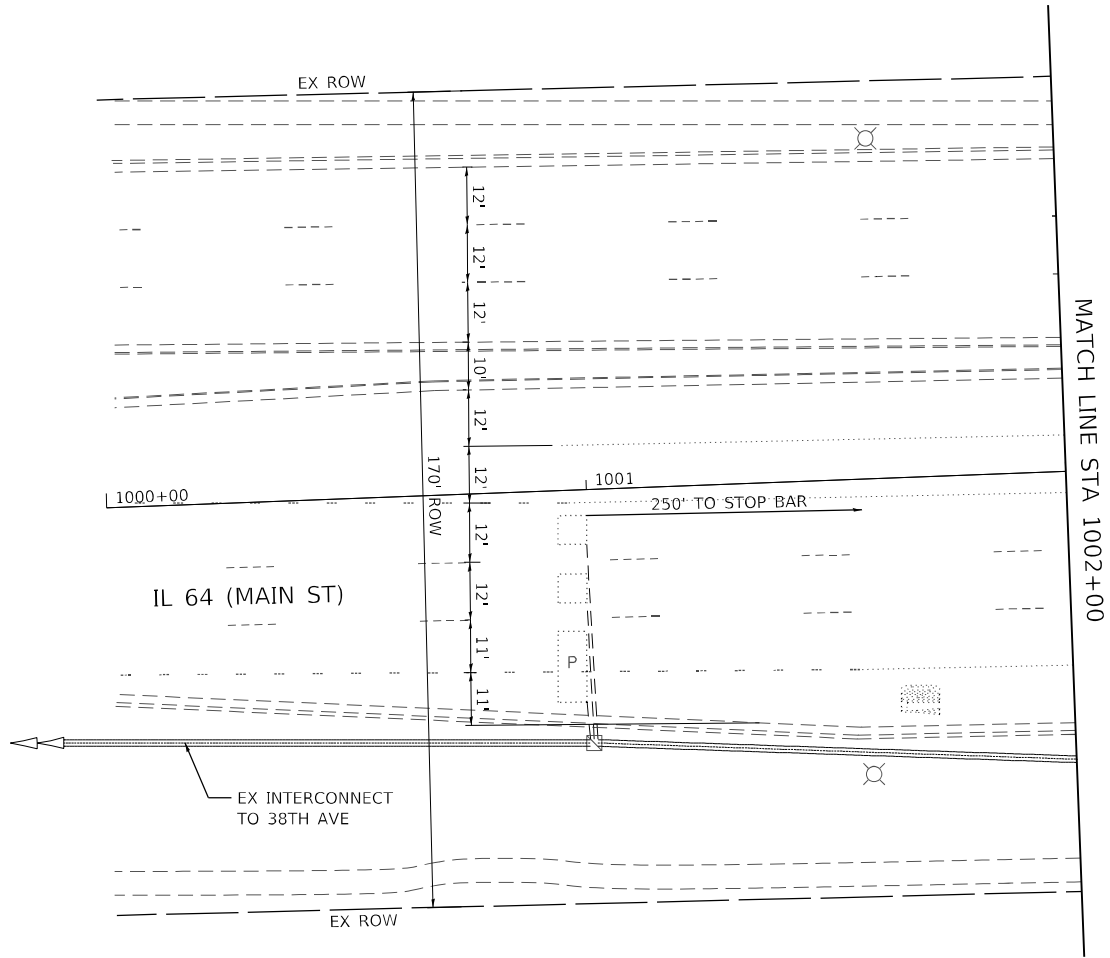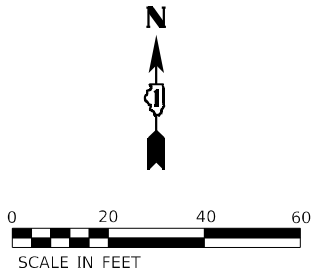

TS 9023
IDOT TACTICS
FORMER EAGLE 2M

MODEL: Default
FILE NAME: p:\sub-pw\bartley.com\k-h-pw-d1\Documents\01 Active Projects\MW-CHS-168950\00 - IL 64\Phase II\2 Design\CAD\Plan Sheets\Signal\West Corridor Signal\01081714-IL-64-02_KH.dgn



USER NAME =	DESIGNED -	REVISED -
	DRAWN -	REVISED -
PLOT SCALE =	CHECKED -	REVISED -
PLOT DATE =	DATE -	REVISED -

STATE OF ILLINOIS
DEPARTMENT OF TRANSPORTATION

TRAFFIC SIGNAL EQUIPMENT REMOVAL PLAN
IL 64 (MAIN ST) AND SMITH RD/KAUTZ RD

SCALE: 1" = 20' SHEET OF SHEETS STA. TO STA.

F.A.P. RTE.	SECTION	COUNTY	TOTAL SHEETS	SHEET NO.
307	2020-263-SUR,SW&TS	DUPAGE	529	105
CONTRACT NO. 62N33				
		ILLINOIS	FED. AID PROJECT	

A
LEFT ON
GREEN
ARROW
ONLY

R10-5
30" X 36"
(4 REQUIRED)

DRILL EX HANDHOLE (1)

9'-UC-2"

PR 5' PEDESTRIAN POST - 12" DIA. FDN (4' DEPTH)
APPROX. STA. 1003+86, 94 LT

23'-E-3"

44' MA

SMITH RD

120'-E-4"

20'-E-3"

EX 36" DIA. FDN

272'-E-2"

APS

32' MA

55' MA

IL 64 (MAIN ST)

250' TO STOP BAR

MATCH LINE STA 1002+00

EX ROW

12'

12'

13'

12'

12'

13'

12'

12'

COMMUNICATIONS VAULT
(SEE INTERCONNECT AND
COMMUNICATIONS PLANS)

89'-E-2"

242'-E-2"

EX ROW

PR CONTROLLER, TERMINAL SERVER,
LAYER III SWITCH, FIBER OPTIC
INTERCONNECT CENTER, 48 PORT IN
EX CABINET, REMOVE AND REPLACE
BATTERIES FOR UPS,

10'-E-4-4"

EX SPARE CONDUIT WITH CAP

21'-E-3"

82'-E-2"

32' MA

APS

64' MA

149'-E-4"

40' MA

EX 42" DIA. FDN

10'-E-3"

EX ROW

EX ROW

12'

12'

12'

13'

12'

12'

116' ROW

KAUTZ RD

CCTV-NO-000

68' MA

APS

95'-E-2"

EX ROW

EX ROW

NOTES

1. ALL PROPOSED TRAFFIC SIGNAL CABLE SHALL BE ROUTED THROUGH THE PROPOSED CONDUIT.
2. A SEPARATE LEAD-IN CABLE SHALL BE INSTALLED FOR THE DETECTOR LOOPS ON IL 64 (NORTH AVE).
3. THERE SHALL BE A MINIMUM OF 4' SIDEWALK CLEARANCE IN FRONT/BEHIND OF THE TRAFFIC SIGNAL FOUNDATIONS TO BE ADA COMPLIANT.
4. THE SIDEWALK CURBS ON ALL QUADRANTS SHALL BE CUT SO THAT THE POST AND MAST ARM FOUNDATIONS ARE FLUSH WITH THE EDGE OF THE SIDEWALK.
5. ALL PUSH BUTTONS SHALL BE APS.
6. THIS LOCATION HAS BEEN DESIGNED TO BE ADA COMPLIANT. ANY DEVIATION FROM THIS PLAN FOR THE POSTS THAT HAVE PEDESTRIAN EQUIPMENT WILL HAVE TO BE APPROVED BY THE ENGINEER TO ENSURE ADA COMPLIANCE.
7. CONTRACTOR SHALL VERIFY THAT THE PLACEMENT OF THE PROPOSED SIGNAL EQUIPMENT ADJACENT TO EXISTING RAMPS MEET ADA REQUIREMENTS. THE ENGINEER SHALL APPROVE THE PROPOSED LOCATIONS OF THE SIGNAL EQUIPMENT BEFORE INSTALLATION.

TS 9023
IDOT TACTICS
FORMER EAGLE 2M

KimleyHorn

© 2023 KIMLEY-HORN AND ASSOCIATES, INC.
4001 WILMINGTON ROAD, SUITE 600
WARREN, IL 60555
PHONE: (847) 455-4555
WWW.KIMLEY-HORN.COM

USER NAME =
DESIGNED -
DRAWN -
PLOT SCALE =
PLOT DATE =

DESIGNED -
DRAWN -
CHECKED -
DATE -



REVISED -
REVISED -
REVISED -
REVISED -

STATE OF ILLINOIS
DEPARTMENT OF TRANSPORTATION

TRAFFIC SIGNAL MODERNIZATION PLAN
IL 64 (MAIN ST) AND SMITH RD/KAUTZ RD

SCALE: 1" = 20' SHEET OF SHEETS STA. TO STA.

F.A.P. RTE.	SECTION	COUNTY	TOTAL SHEETS	SHEET NO.
307	2020-263-SUR, SW&TS	DUPAGE	529	106
				CONTRACT NO. 62N33
		ILLINOIS	FED. AID PROJECT	

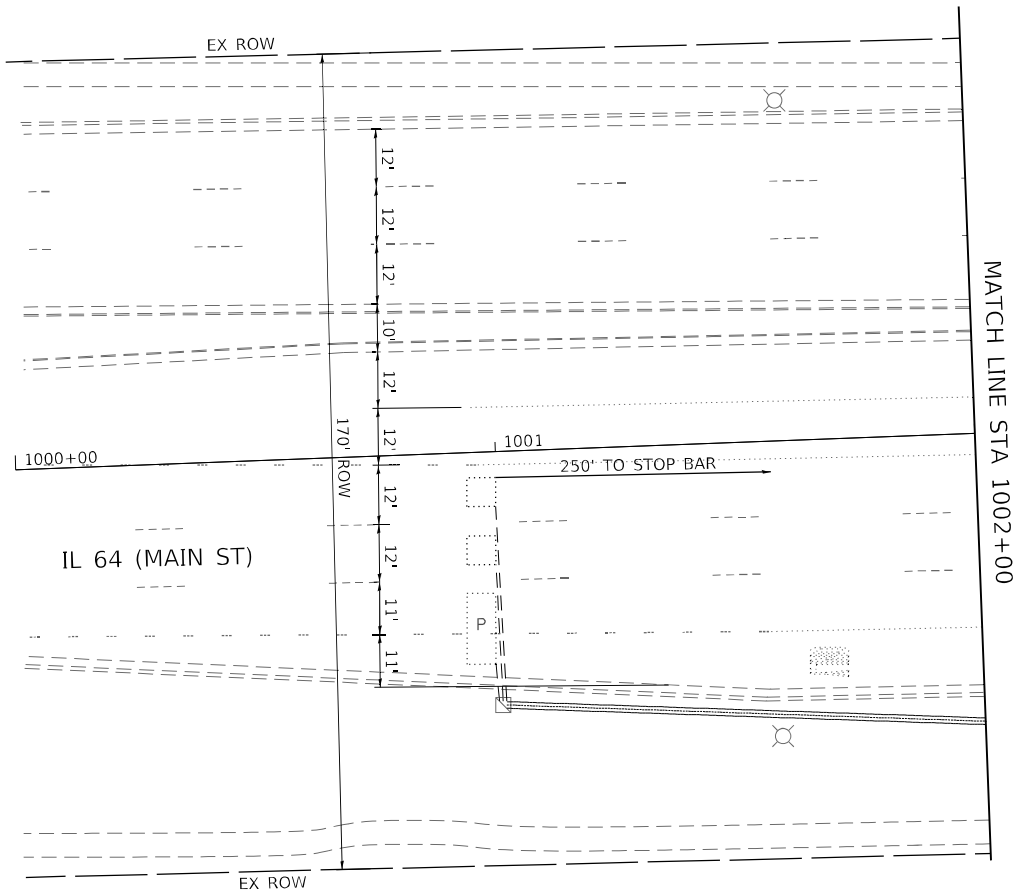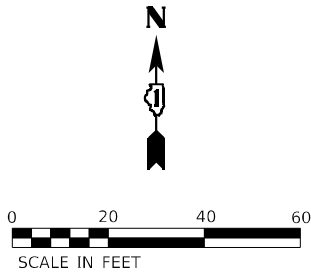

MODEL: Default
FILE NAME: p:\sub-pw\bartley.com\k-h-pw-d1\Documents\01 Active Projects\MW\CL-S-160950\00 - IL 64\Phase II\2 Design\CAD\Plan Sheets\Signal\West Corridor Signal\01081714-IL-64-K4A.dgn



USER NAME =	DESIGNED -	REVISED -
	DRAWN -	REVISED -
PLOT SCALE =	CHECKED -	REVISED -
PLOT DATE =	DATE -	REVISED -


STATE OF ILLINOIS
DEPARTMENT OF TRANSPORTATION

TRAFFIC SIGNAL MODERNIZATION PLAN IL 64 (MAIN ST) AND SMITH RD/KAUTZ RD			
SCALE: 1" = 20'	SHEET	OF	SHEETS
	STA.	TO	STA.


F.A.P. RTE.	SECTION	COUNTY	TOTAL SHEETS	SHEET NO.
307	2020-263-SUR,SW&TS	DUPAGE	529	107
CONTRACT NO. 62N33				
		ILLINOIS	FED. AID PROJECT	

TS 9023
IDOT TACTICS
FORMER EAGLE 2M

EXISTING AND PROPOSED CONTROLLER SEQUENCE

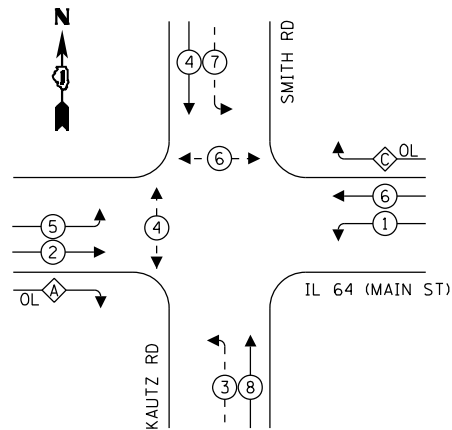


LEGEND:

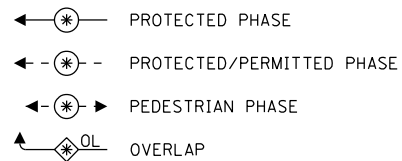

OVERLAP LETTER		PERMISSIVE PHASE		PROTECTED PHASE
A	=	2	+	3
C	=	6	+	7

EXISTING AND PROPOSED EMERGENCY VEHICLE PREEMPTION SEQUENCE

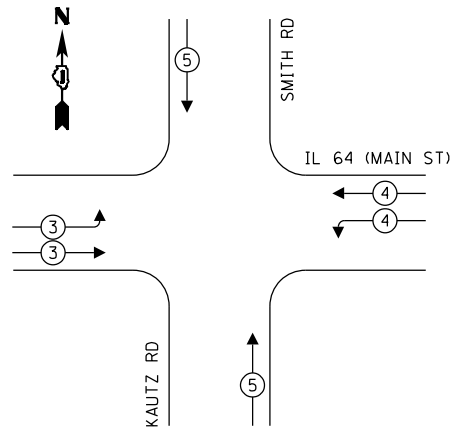

TRAFFIC SIGNAL ELECTRICAL SERVICE REQUIREMENTS

TYPE	QUANTITY	UNIT WATTAGE	TOTAL WATTAGE
SIGNAL HEAD 1 OR 3-SECTION	14	11	154
4-SECTION	-	14	-
5-SECTION	8	13	104
PROGRAMMABLE 3-SECTION	-	22	-
4-SECTION	-	32	-
5-SECTION	-	28	-
PEDESTRIAN SIGNAL	4	15	60
CONTROLLER	1	150	150
MASTER CONTROLLER	-	100	-
UPS	1	25	25
DETECTION VIDEO	2	20	40
BLANK-OUT SIGN	-	25	-
NETWORK SWITCH LAYER II OR III	1	35	35
CELLULAR MODEM	-	15	-
PTZ	1	75	75
TOTAL UPS SIZING			643
UPS CHARGING	1	225	225
BATTERY HEATER MAT	1	180	180
CABINET HEATER	1	200	200
FLASHER	-	15	-
LED STREET NAME SIGN	-	120	-
LUMINAIRE	5	240	1200
TOTAL SERVICE WIRE SIZING			2448

LEGEND:

L = LED LAMP MODULE REPLACEMENT
* = ROADWAY LIGHTING CABLE

ENERGY COSTS TO:
CITY OF ST. CHARLES
2 E MAIN ST
ST. CHARLES, IL 60174

ENERGY SUPPLY: COMPANY: ST. CHARLES ELEC. DEPT.
PHONE: (630) 377-4407
ACCOUNT NUMBER: _____

CABLE PLAN

(NOT TO SCALE)

TS 9023
IDOT TACTICS
FORMER EAGLE 2M

**STATE OF ILLINOIS
DEPARTMENT OF TRANSPORTATION**




**CABLE PLAN, PHASE DESIGNATION DIAGRAM, AND
EMERGENCY VEHICLE PREEMPTION SEQUENCE
IL 64 (MAIN ST) AND SMITH RD/KAUTZ RD**

SCALE: N.T.S.	SHEET	OF	SHEETS	STA.	TO STA.
---------------	-------	----	--------	------	---------

F.A.P. RTE.	SECTION	COUNTY	TOTAL SHEETS	SHEET NO.
307	2020-263-SUR, SW&TS	DUPAGE	529	108
		CONTRACT NO. 62N33		
		ILLINOIS FED. AID PROJECT		

MODEL: Default
FILE NAME: pw:\kh-pw\bentlev.com\kh-pw\01\Documents\01 Active Projects\MW-CHS-16899\100 - IL 64\Phase II\2 Design\CAD\Plan Sheets\Signal\SignalWest Corridor Signal\ID10812 L-sht-ts-05 KHA.dgn

   
ALL DIMENSIONS ARE IN INCHES UNLESS OTHERWISE NOTED



ITEM DESCRIPTION	UNIT	QUANTITY
SIGN PANEL - TYPE 2	SQ FT	87.5
MAINTENANCE OF EXISTING TRAFFIC SIGNAL INSTALLATION	EACH	1
ELECTRIC CABLE IN CONDUIT, SIGNAL NO. 14 2C	FOOT	248
ELECTRIC CABLE IN CONDUIT, LEAD-IN, NO. 14 1 PAIR	FOOT	555
DRILL EXISTING HANDHOLE	EACH	1
INDUCTIVE LOOP DETECTOR	EACH	2
REMOVE EXISTING TRAFFIC SIGNAL EQUIPMENT	EACH	1
REMOVE EXISTING HANDHOLE	EACH	2
CLOSED CIRCUIT TELEVISION DOME CAMERA, HD	EACH	1
TERMINAL SERVER	EACH	1
LED LAMP MODULE REPLACEMENT	EACH	82
OUTDOOR RATED NETWORK CABLE	FOOT	221
REMOTE CONTROLLED VIDEO SYSTEM	EACH	1
TERMINATE FIBER IN CABINET	EACH	36
PEDESTRIAN SIGNAL POST, 5 FT.	EACH	1
LAYER III (NETWORK) SWITCH	EACH	1
TACTICS LICENSE EXPANSION	EACH	1
FULL-ACTUATED CONTROLLER IN EXISTING CABINET	EACH	1
REMOVE AND REPLACE BATTERIES FOR UNINTERRUPTABLE POWER SUPPLY, EXTENDED	EACH	1
FIBER OPTIC INTERCONNECT CENTER, 48 PORT	EACH	1
ACCESSIBLE PEDESTRIAN SIGNALS	EACH	4
CONCRETE FOUNDATION, TYPE A 12-INCH DIAMETER	FOOT	4
LED SIGNAL FACE, LENS COVER	EACH	22
LED PEDESTRIAN SIGNAL MODULE REPLACEMENT	EACH	12
VIDEO VEHICLE DETECTION SYSTEM, SINGLE APPROACH	EACH	2
CAMERA MOUNTING ASSEMBLY	EACH	1

NOTES

- THE EXISTING TRAFFIC SIGNAL EQUIPMENT SHALL NOT BE REMOVED UNTIL THE PROPOSED TRAFFIC SIGNAL EQUIPMENT IS FULLY OPERATIONAL OR AS DIRECTED BY THE ENGINEER.
- ALL EXISTING TRAFFIC SIGNAL CABLE NO LONGER REQUIRED SHALL BE REMOVED.

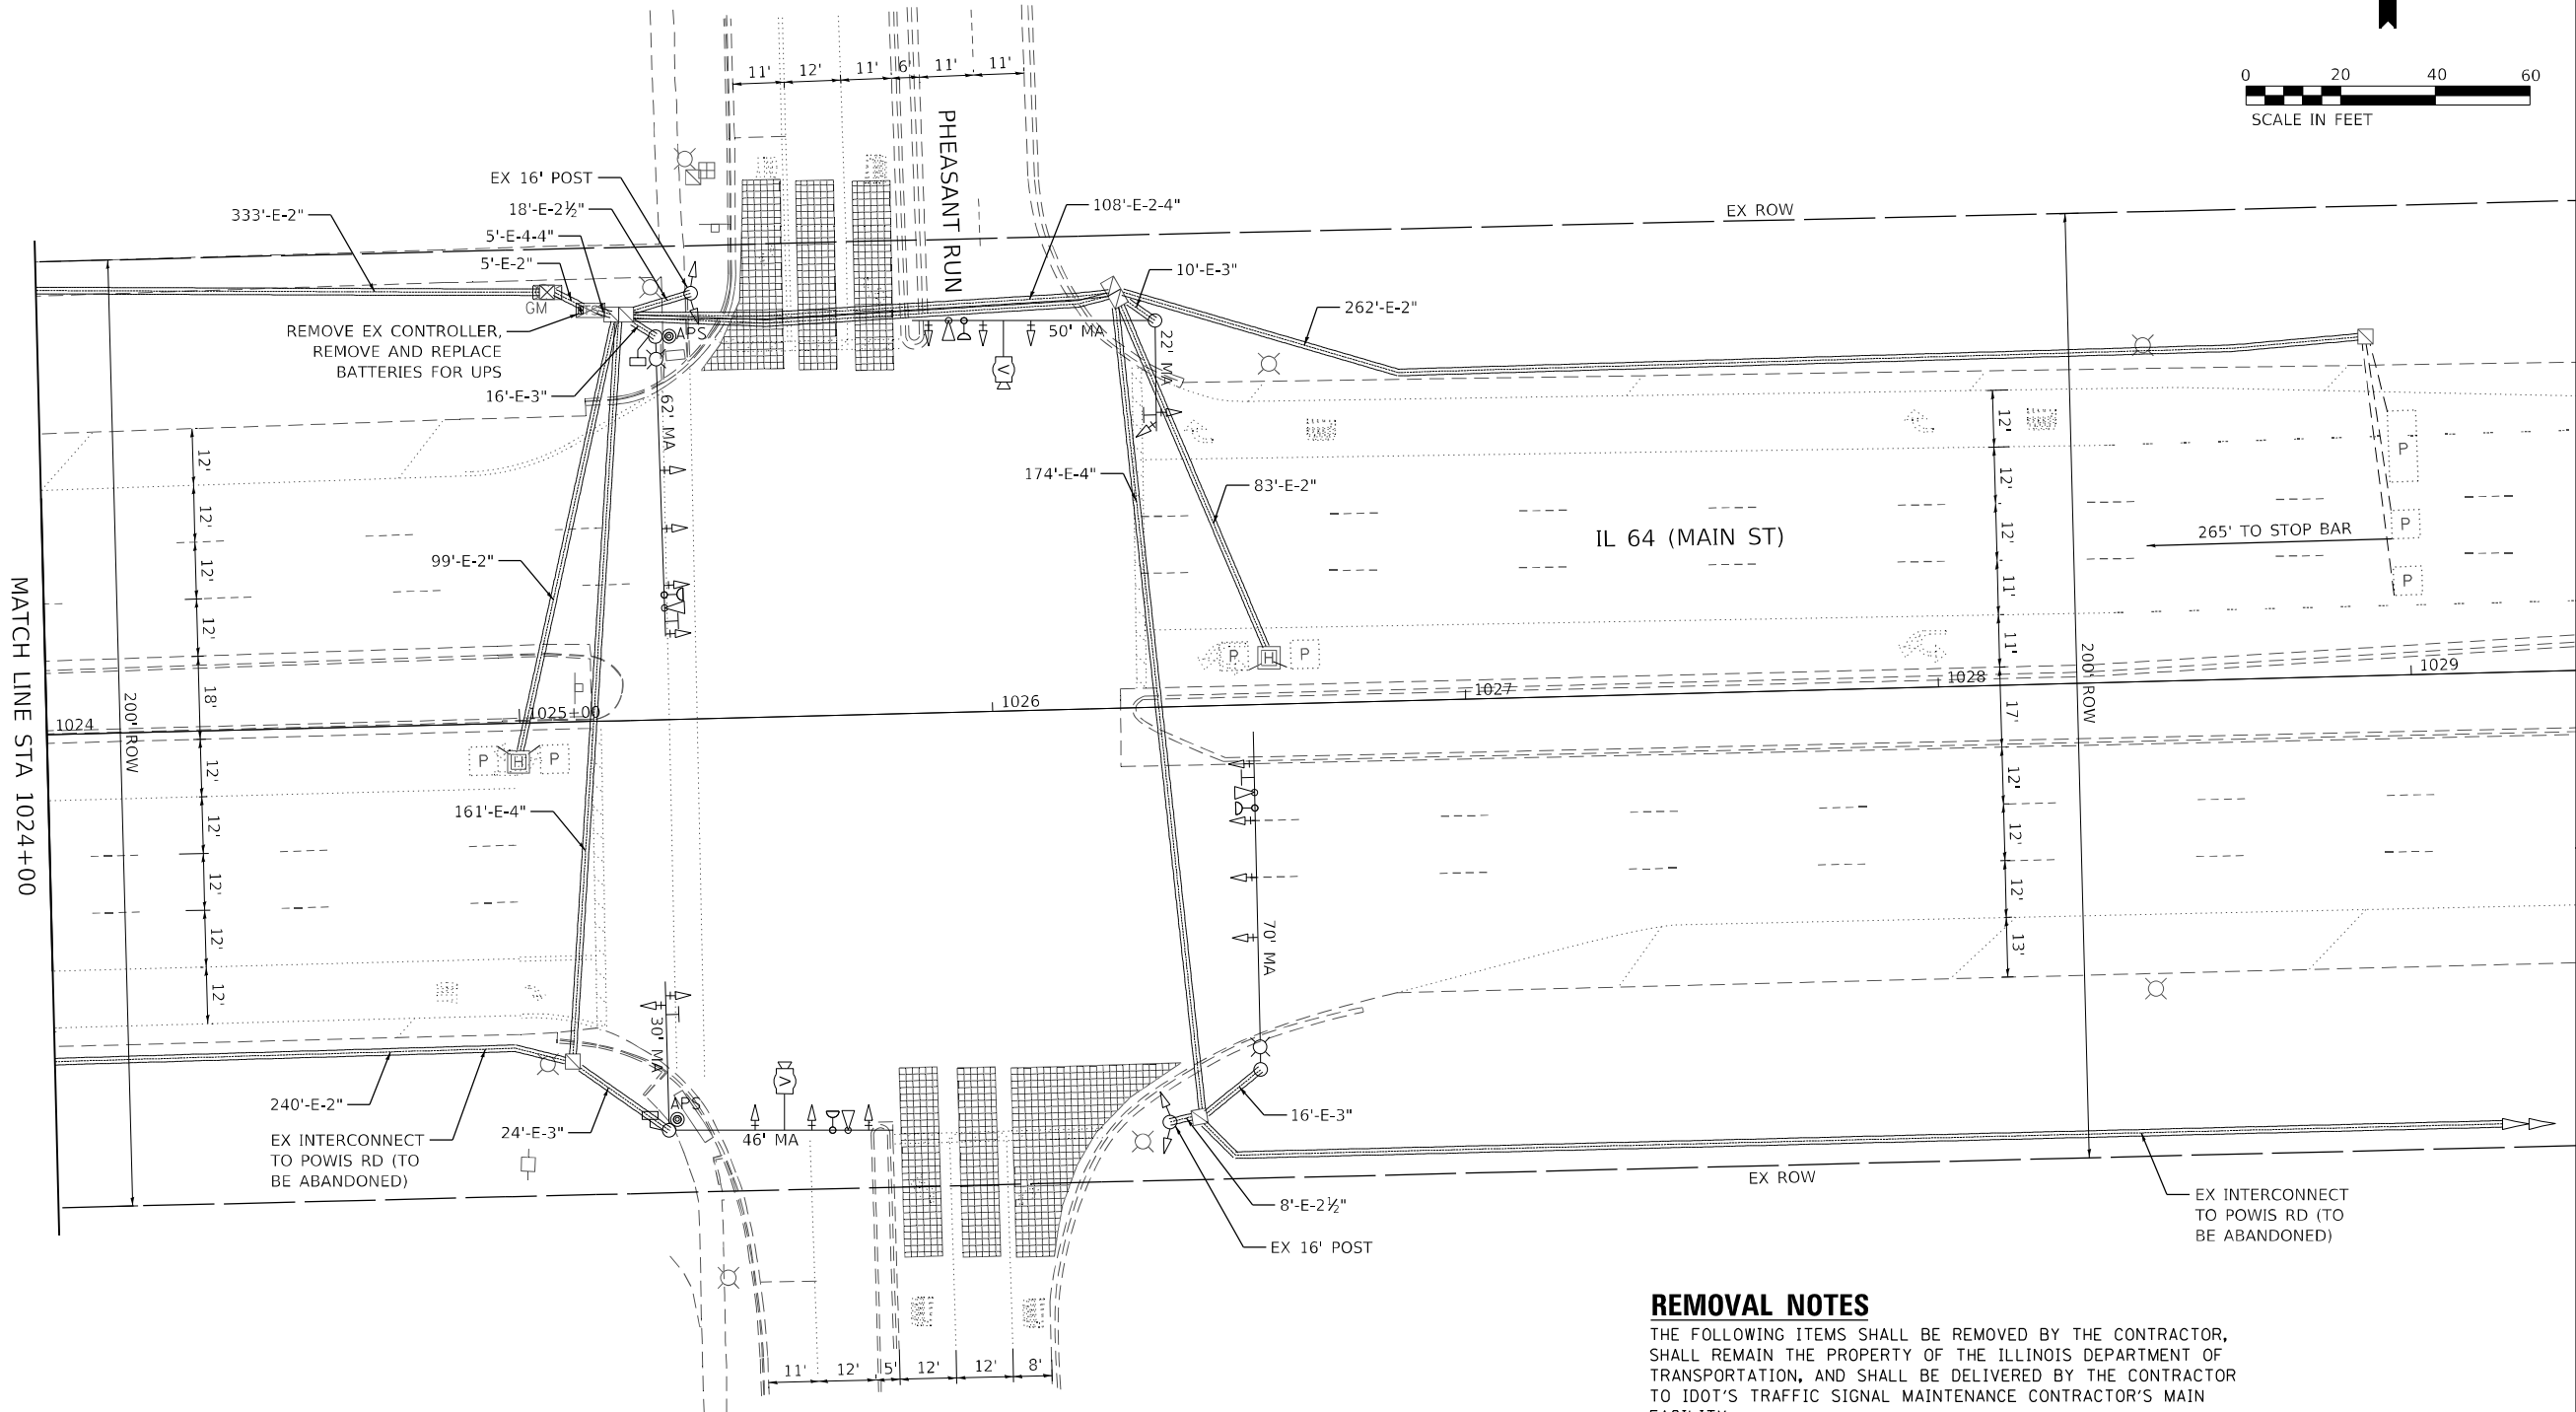

REMOVAL NOTES

THE FOLLOWING ITEMS SHALL BE REMOVED BY THE CONTRACTOR, SHALL REMAIN THE PROPERTY OF THE ILLINOIS DEPARTMENT OF TRANSPORTATION, AND SHALL BE DELIVERED BY THE CONTRACTOR TO IDOT'S TRAFFIC SIGNAL MAINTENANCE CONTRACTOR'S MAIN FACILITY.

1 EACH CONTROLLER (M52)

TS 9024
IDOT TACTICS
FORMER EAGLE 2M



© 2023 KIMLEY-HORN AND ASSOCIATES, INC.
4001 WILMINGTON ROAD, SUITE 600
WARREN, ILL. 60555
PHONE: (847) 455-4555
WWW.KIMLEY-HORN.COM



USER NAME =	DESIGNED -	REVISED -
	DRAWN -	REVISED -
PLOT SCALE =	CHECKED -	REVISED -
PLOT DATE =	DATE -	REVISED -

STATE OF ILLINOIS
DEPARTMENT OF TRANSPORTATION

TRAFFIC SIGNAL EQUIPMENT REMOVAL PLAN
IL 64 (MAIN ST) AND PHEASANT RUN

SCALE: 1" = 20' SHEET OF SHEETS STA. TO STA.

F.A.P. RTE.	SECTION	COUNTY	TOTAL SHEETS	SHEET NO.
307	2020-263-SUR, SW&TS	DUPAGE	529	110
				CONTRACT NO. 62N33
		ILLINOIS	FED. AID PROJECT	

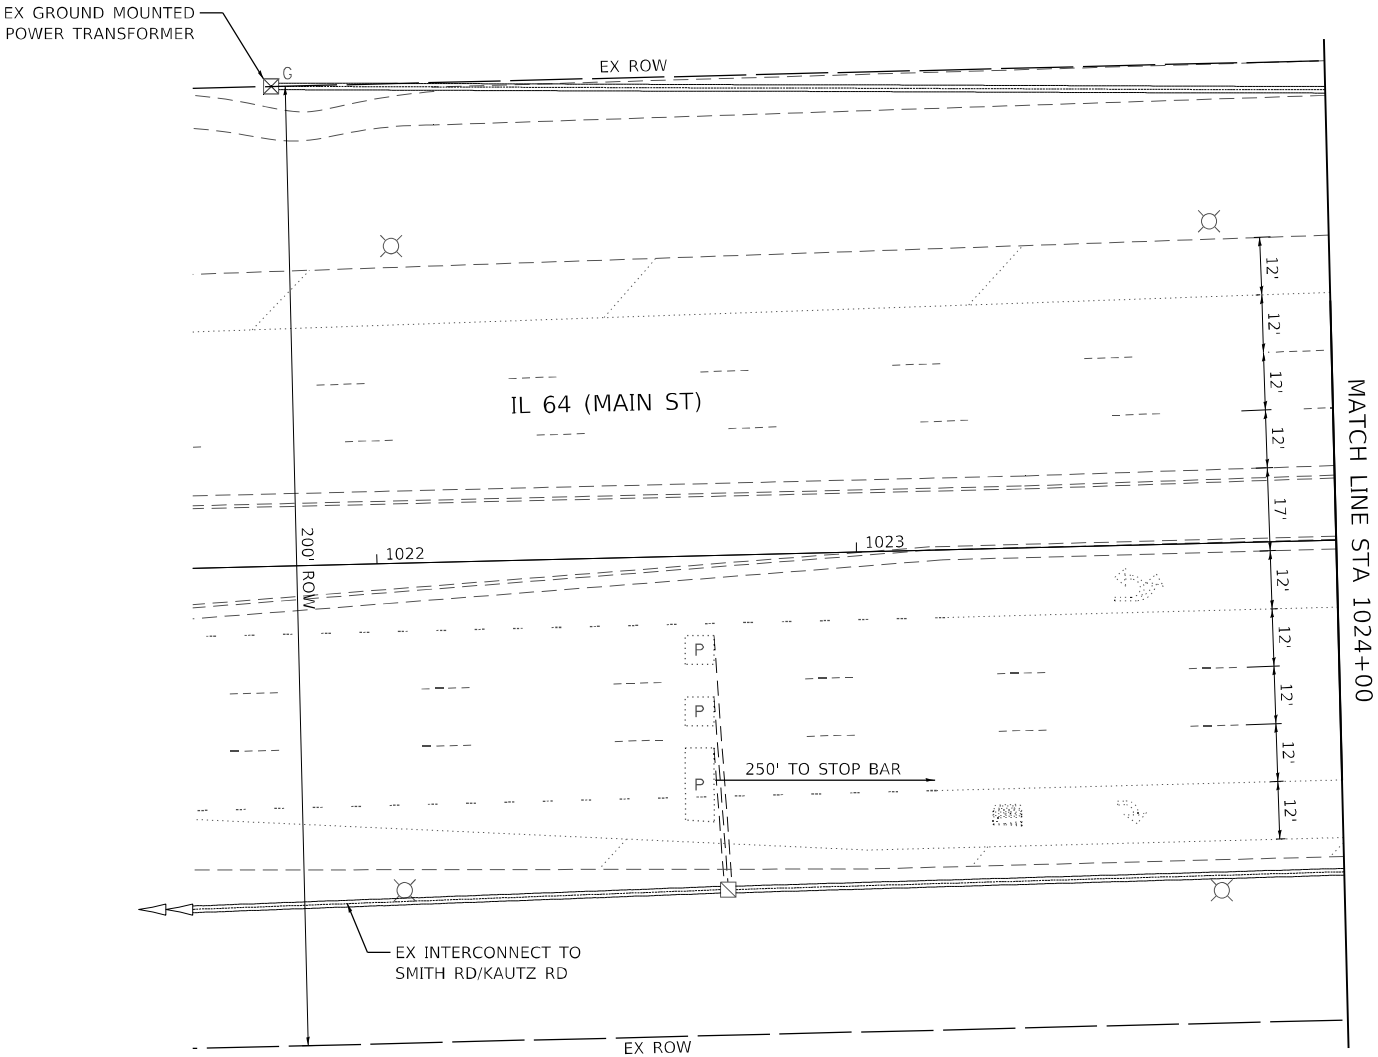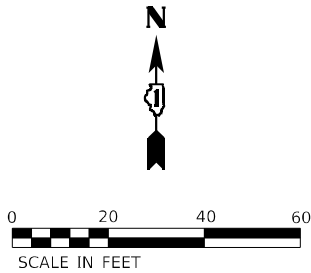

MODEL: Default
FILE NAME: p:\sub-pw\bartley.com\k-h-pw-d\Documents\01 Active Projects\MW\CL-S-160950\00 - IL 64\Phase 1\2 Design\CAD\Plan Sheets\Signal\West Corridor_Signal\01-14-17-16-08_K4A.dgn



USER NAME =	DESIGNED -	REVISED -
	DRAWN -	REVISED -
PLOT SCALE =	CHECKED -	REVISED -
PLOT DATE =	DATE -	REVISED -

STATE OF ILLINOIS
DEPARTMENT OF TRANSPORTATION

TRAFFIC SIGNAL EQUIPMENT REMOVAL PLAN
IL 64 (MAIN ST) AND PHEASANT RUN

SCALE: 1" = 20' SHEET OF SHEETS STA. TO STA.

F.A.P. RTE.	SECTION	COUNTY	TOTAL SHEETS	SHEET NO.
307	2020-263-SUR, SW&TS	DUPAGE	529	111
CONTRACT NO. 62N33				
		ILLINOIS	FED. AID PROJECT	

TS 9024
IDOT TACTICS
FORMER EAGLE 2M


A

LEFT ON
GREEN
ARROW
ONLY

R10-5
30" X 36"
(4 REQUIRED)



0 20 40 60
SCALE IN FEET

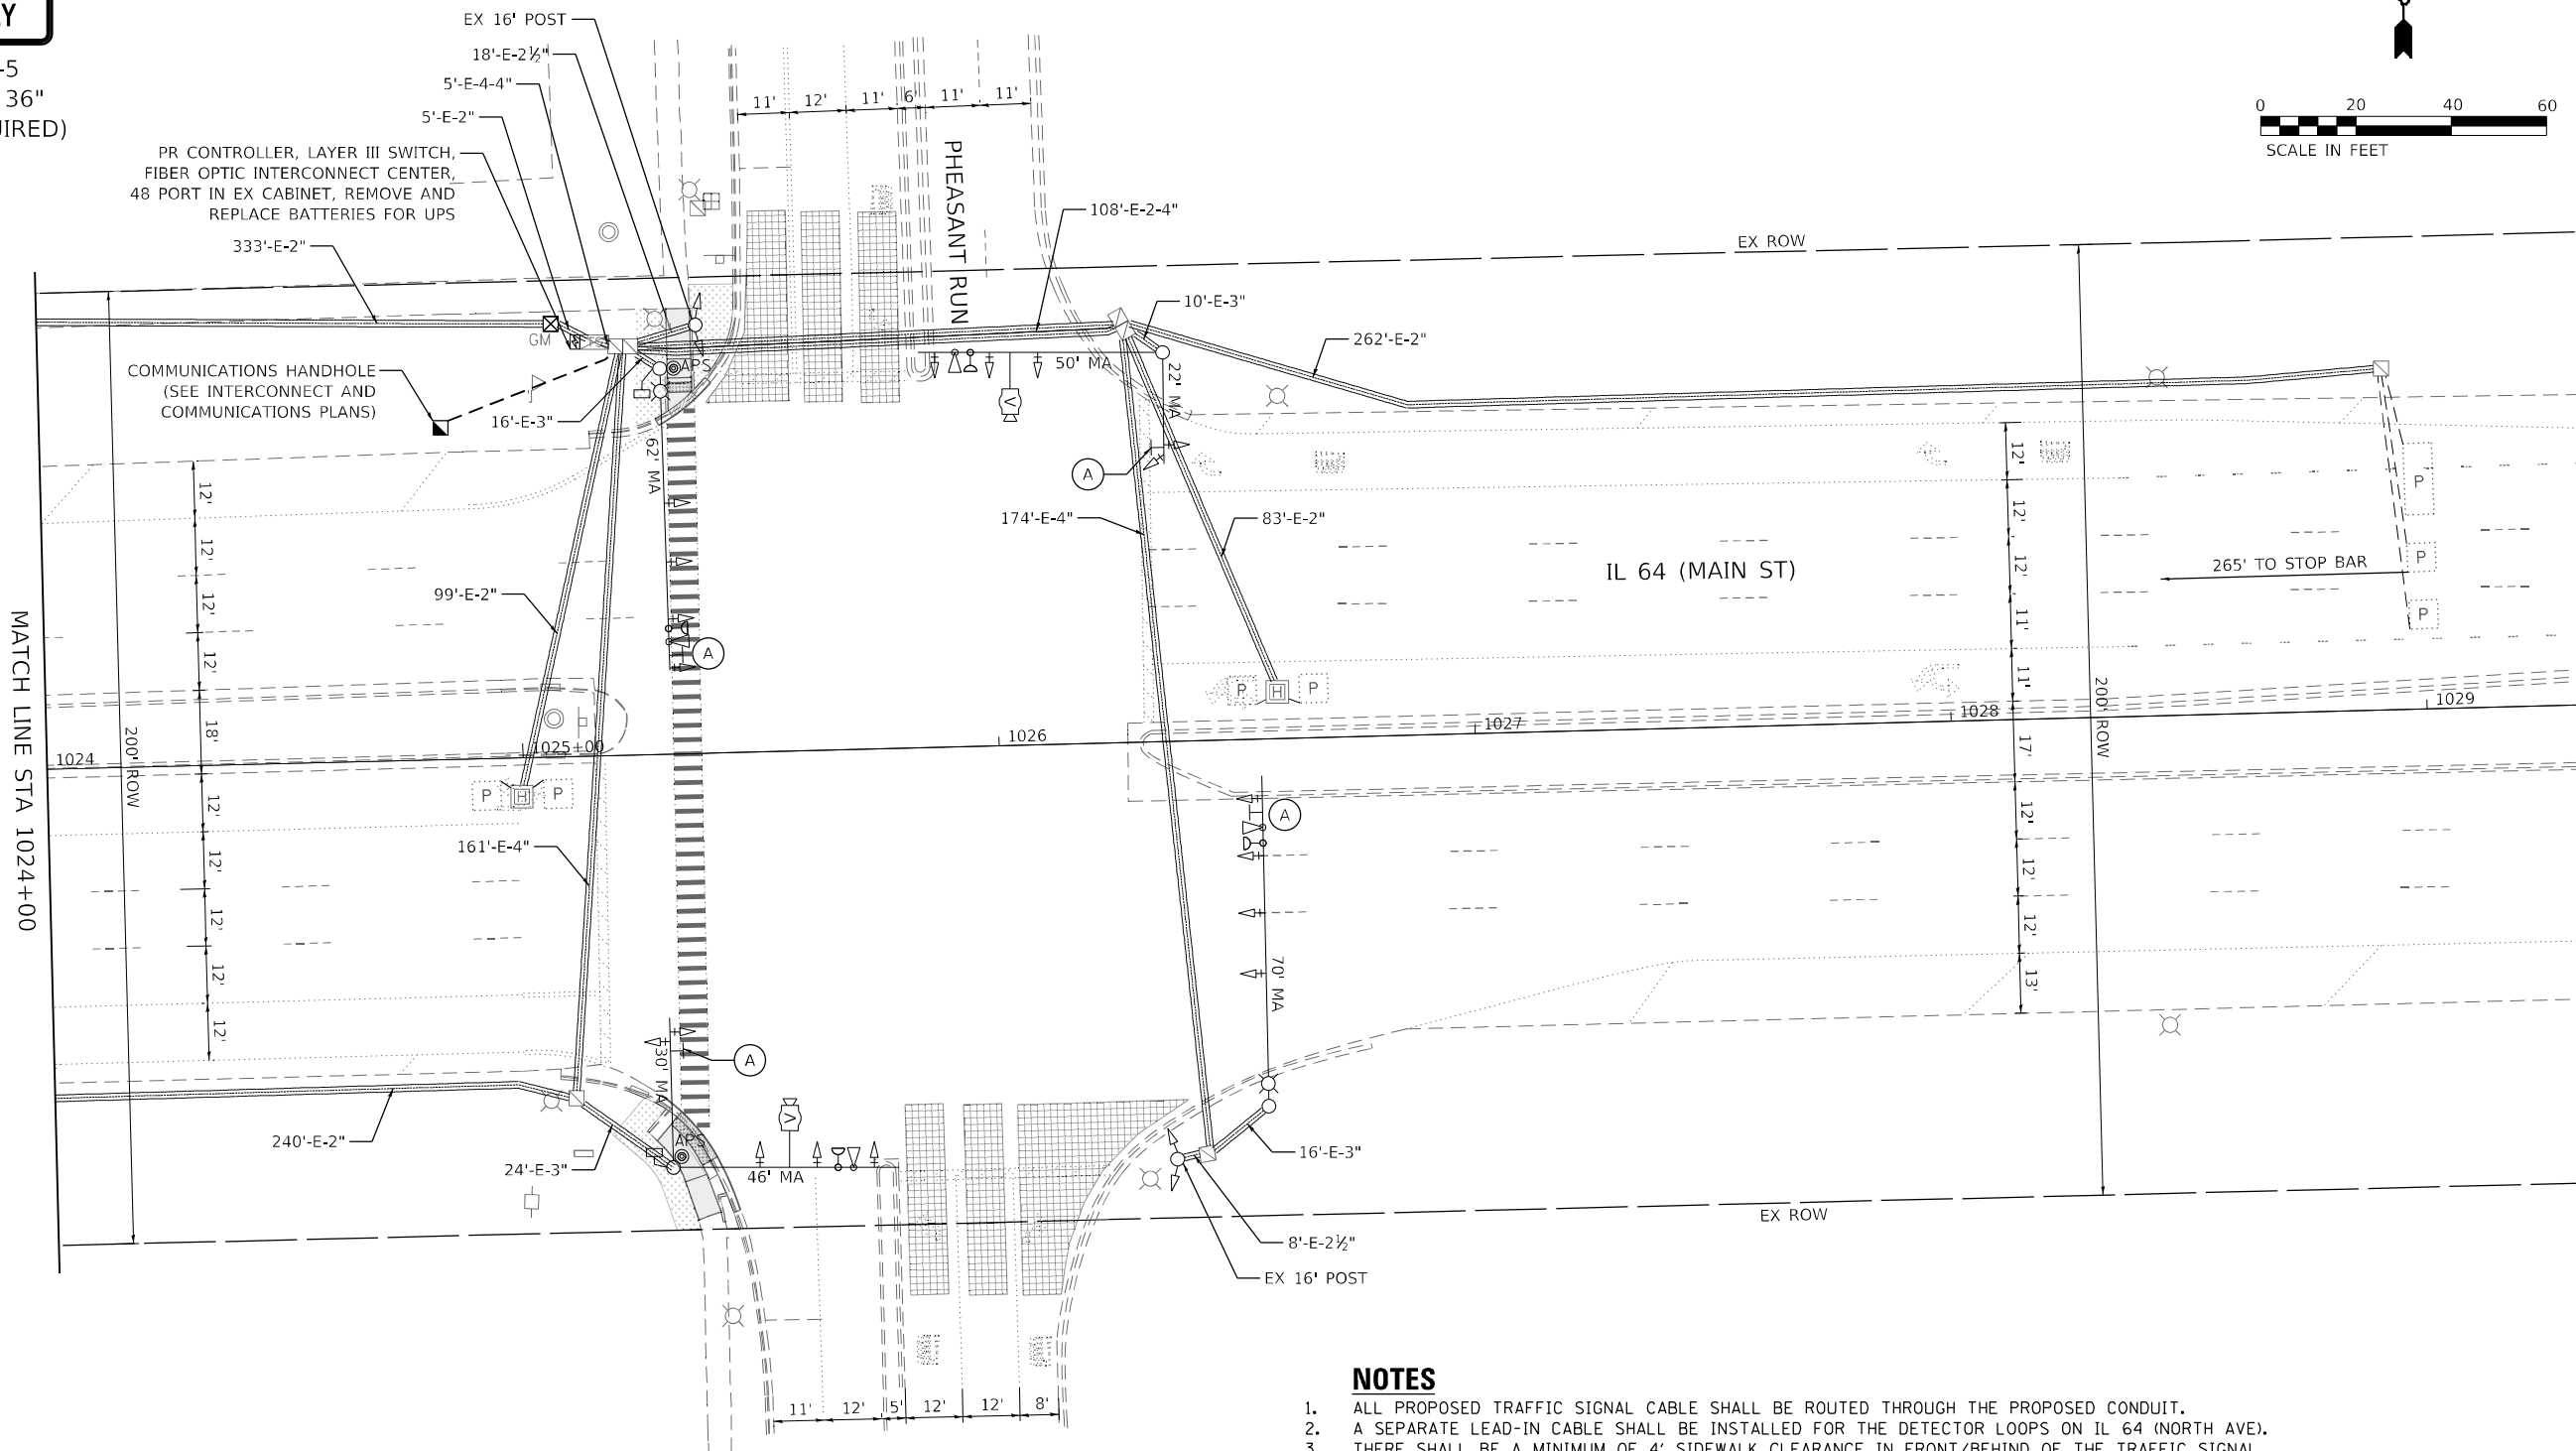

NOTES

1. ALL PROPOSED TRAFFIC SIGNAL CABLE SHALL BE ROUTED THROUGH THE PROPOSED CONDUIT.
2. A SEPARATE LEAD-IN CABLE SHALL BE INSTALLED FOR THE DETECTOR LOOPS ON IL 64 (NORTH AVE).
3. THERE SHALL BE A MINIMUM OF 4' SIDEWALK CLEARANCE IN FRONT/BEHIND OF THE TRAFFIC SIGNAL FOUNDATIONS TO BE ADA COMPLIANT.
4. THE SIDEWALK CURBS ON ALL QUADRANTS SHALL BE CUT SO THAT THE POST AND MAST ARM FOUNDATIONS ARE FLUSH WITH THE EDGE OF THE SIDEWALK.
5. ALL PUSH BUTTONS SHALL BE APS.
6. THIS LOCATION HAS BEEN DESIGNED TO BE ADA COMPLIANT. ANY DEVIATION FROM THIS PLAN FOR THE POSTS THAT HAVE PEDESTRIAN EQUIPMENT WILL HAVE TO BE APPROVED BY THE ENGINEER TO ENSURE ADA COMPLIANCE.
7. CONTRACTOR SHALL VERIFY THAT THE PLACEMENT OF THE PROPOSED SIGNAL EQUIPMENT ADJACENT TO EXISTING RAMPS MEET ADA REQUIREMENTS. THE ENGINEER SHALL APPROVE THE PROPOSED LOCATIONS OF THE SIGNAL EQUIPMENT BEFORE INSTALLATION.

TS 9024
IDOT TACTICS
FORMER EAGLE 2M

Kimley»Horn

© 2023 KIMLEY-HORN AND ASSOCIATES, INC.
4001 WILSON D. ROAD, SUITE 600
WARREN, ILL. 60555
PHONE: (847) 455-4555
WWW.KH.COM

USER NAME =
PLOT SCALE =
PLOT DATE =

DESIGNED -
DRAWN -
CHECKED -
DATE -

REVISED -
REVISED -
REVISED -
REVISED -



STATE OF ILLINOIS
DEPARTMENT OF TRANSPORTATION

TRAFFIC SIGNAL MODERNIZATION PLAN
IL 64 (MAIN ST) AND PHEASANT RUN

SCALE: 1" = 20'

SHEET OF SHEETS STA. TO STA.

F.A.P. RTE.	SECTION	COUNTY	TOTAL SHEETS	SHEET NO.
307	2020-263-SUR, SW&TS	DUPAGE	529	112
CONTRACT NO. 62N33				
ILLINOIS FED. AID PROJECT				

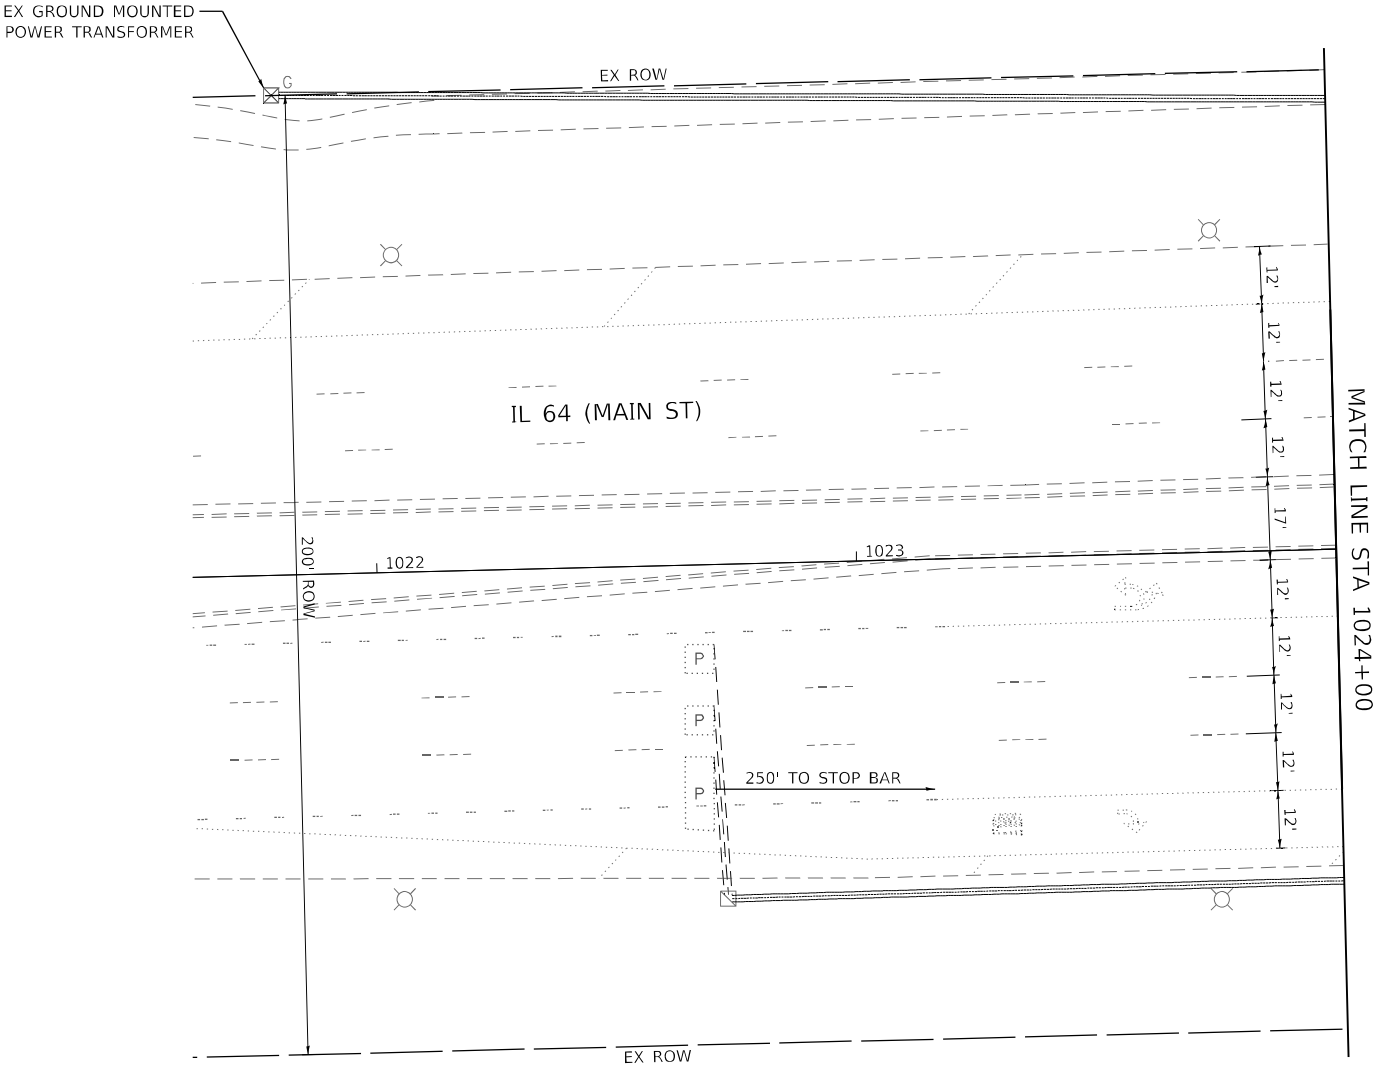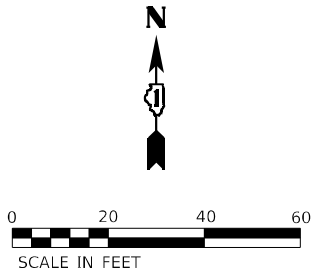

MODEL: Default
FILE NAME: p:\sub-pw\bartley.com\k-h-pw-d\Documents\01 Active Projects\MW\CL-S-160950\00 - IL 64\Phase 1\2 Design\CAD\Plan Sheets\Signal\West Corridor_Signal\01 IL 64-10_K4A.dgn



USER NAME =	DESIGNED -	REVISED -
	DRAWN -	REVISED -
PLOT SCALE =	CHECKED -	REVISED -
PLOT DATE =	DATE -	REVISED -

STATE OF ILLINOIS
DEPARTMENT OF TRANSPORTATION


TRAFFIC SIGNAL MODERNIZATION PLAN
IL 64 (MAIN ST) AND PHEASANT RUN

SCALE: 1" = 20' SHEET OF SHEETS STA. TO STA.

F.A.P. RTE.	SECTION	COUNTY	TOTAL SHEETS	SHEET NO.
307	2020-263-SUR,SW&TS	DUPAGE	529	113
CONTRACT NO. 62N33				
ILLINOIS FED. AID PROJECT				

TS 9024
IDOT TACTICS
FORMER EAGLE 2M

EXISTING AND PROPOSED
CONTROLLER SEQUENCE

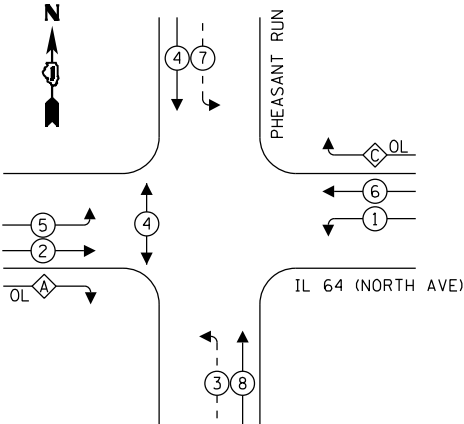


LEGEND:

- ← (*) PROTECTED PHASE
- ← (*) - PROTECTED/PERMITTED PHASE
- ← (*) → PEDESTRIAN PHASE
- ← (*) OL OVERLAP

OVERLAP LETTER	PERMISSIVE PHASE	PROTECTED PHASE
A	= 2	+ 3
C	= 6	+ 7

EXISTING AND PROPOSED EMERGENCY
VEHICLE PREEMPTION SEQUENCE

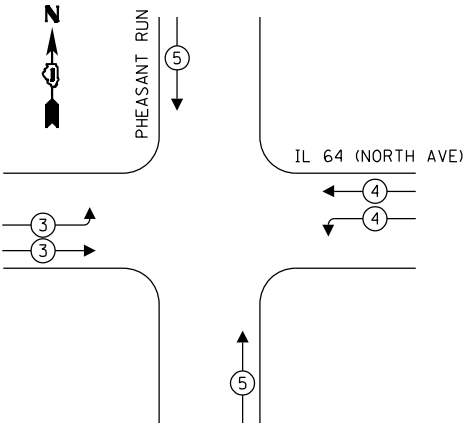

TRAFFIC SIGNAL
ELECTRICAL SERVICE REQUIREMENTS

TYPE	QUANTITY	UNIT WATTAGE	TOTAL WATTAGE
SIGNAL HEAD 1 OR 3-SECTION	14	11	154
4-SECTION	-	14	-
5-SECTION	8	13	104
PROGRAMMABLE 3-SECTION	-	22	-
4-SECTION	-	32	-
5-SECTION	-	28	-
PEDESTRIAN SIGNAL	2	15	30
CONTROLLER	1	150	150
MASTER CONTROLLER	-	100	-
UPS	1	25	25
DETECTION VIDEO	2	20	40
BLANK-OUT SIGN	-	25	-
NETWORK SWITCH LAYER II OR III	1	35	35
CELLULAR MODEM	-	15	-
PTZ	-	75	-
TOTAL UPS SIZING			538
UPS CHARGING	1	225	225
BATTERY HEATER MAT	1	180	180
CABINET HEATER	1	200	200
FLASHER	-	15	-
LED STREET NAME SIGN	-	120	-
LUMINAIRE	-	240	-
TOTAL SERVICE WIRE SIZING			1143


ENERGY COSTS TO:
CITY OF ST. CHARLES
2 E MAIN ST
ST. CHARLES, IL 60174

ENERGY SUPPLY: CONTACT: STEVE SHROBA
PHONE: (630) 377-4475
ACCOUNT NUMBER: _____

LEGEND:

- L = LED LAMP MODULE REPLACEMENT
- * = ROADWAY LIGHTING CABLE

CABLE PLAN
(NOT TO SCALE)

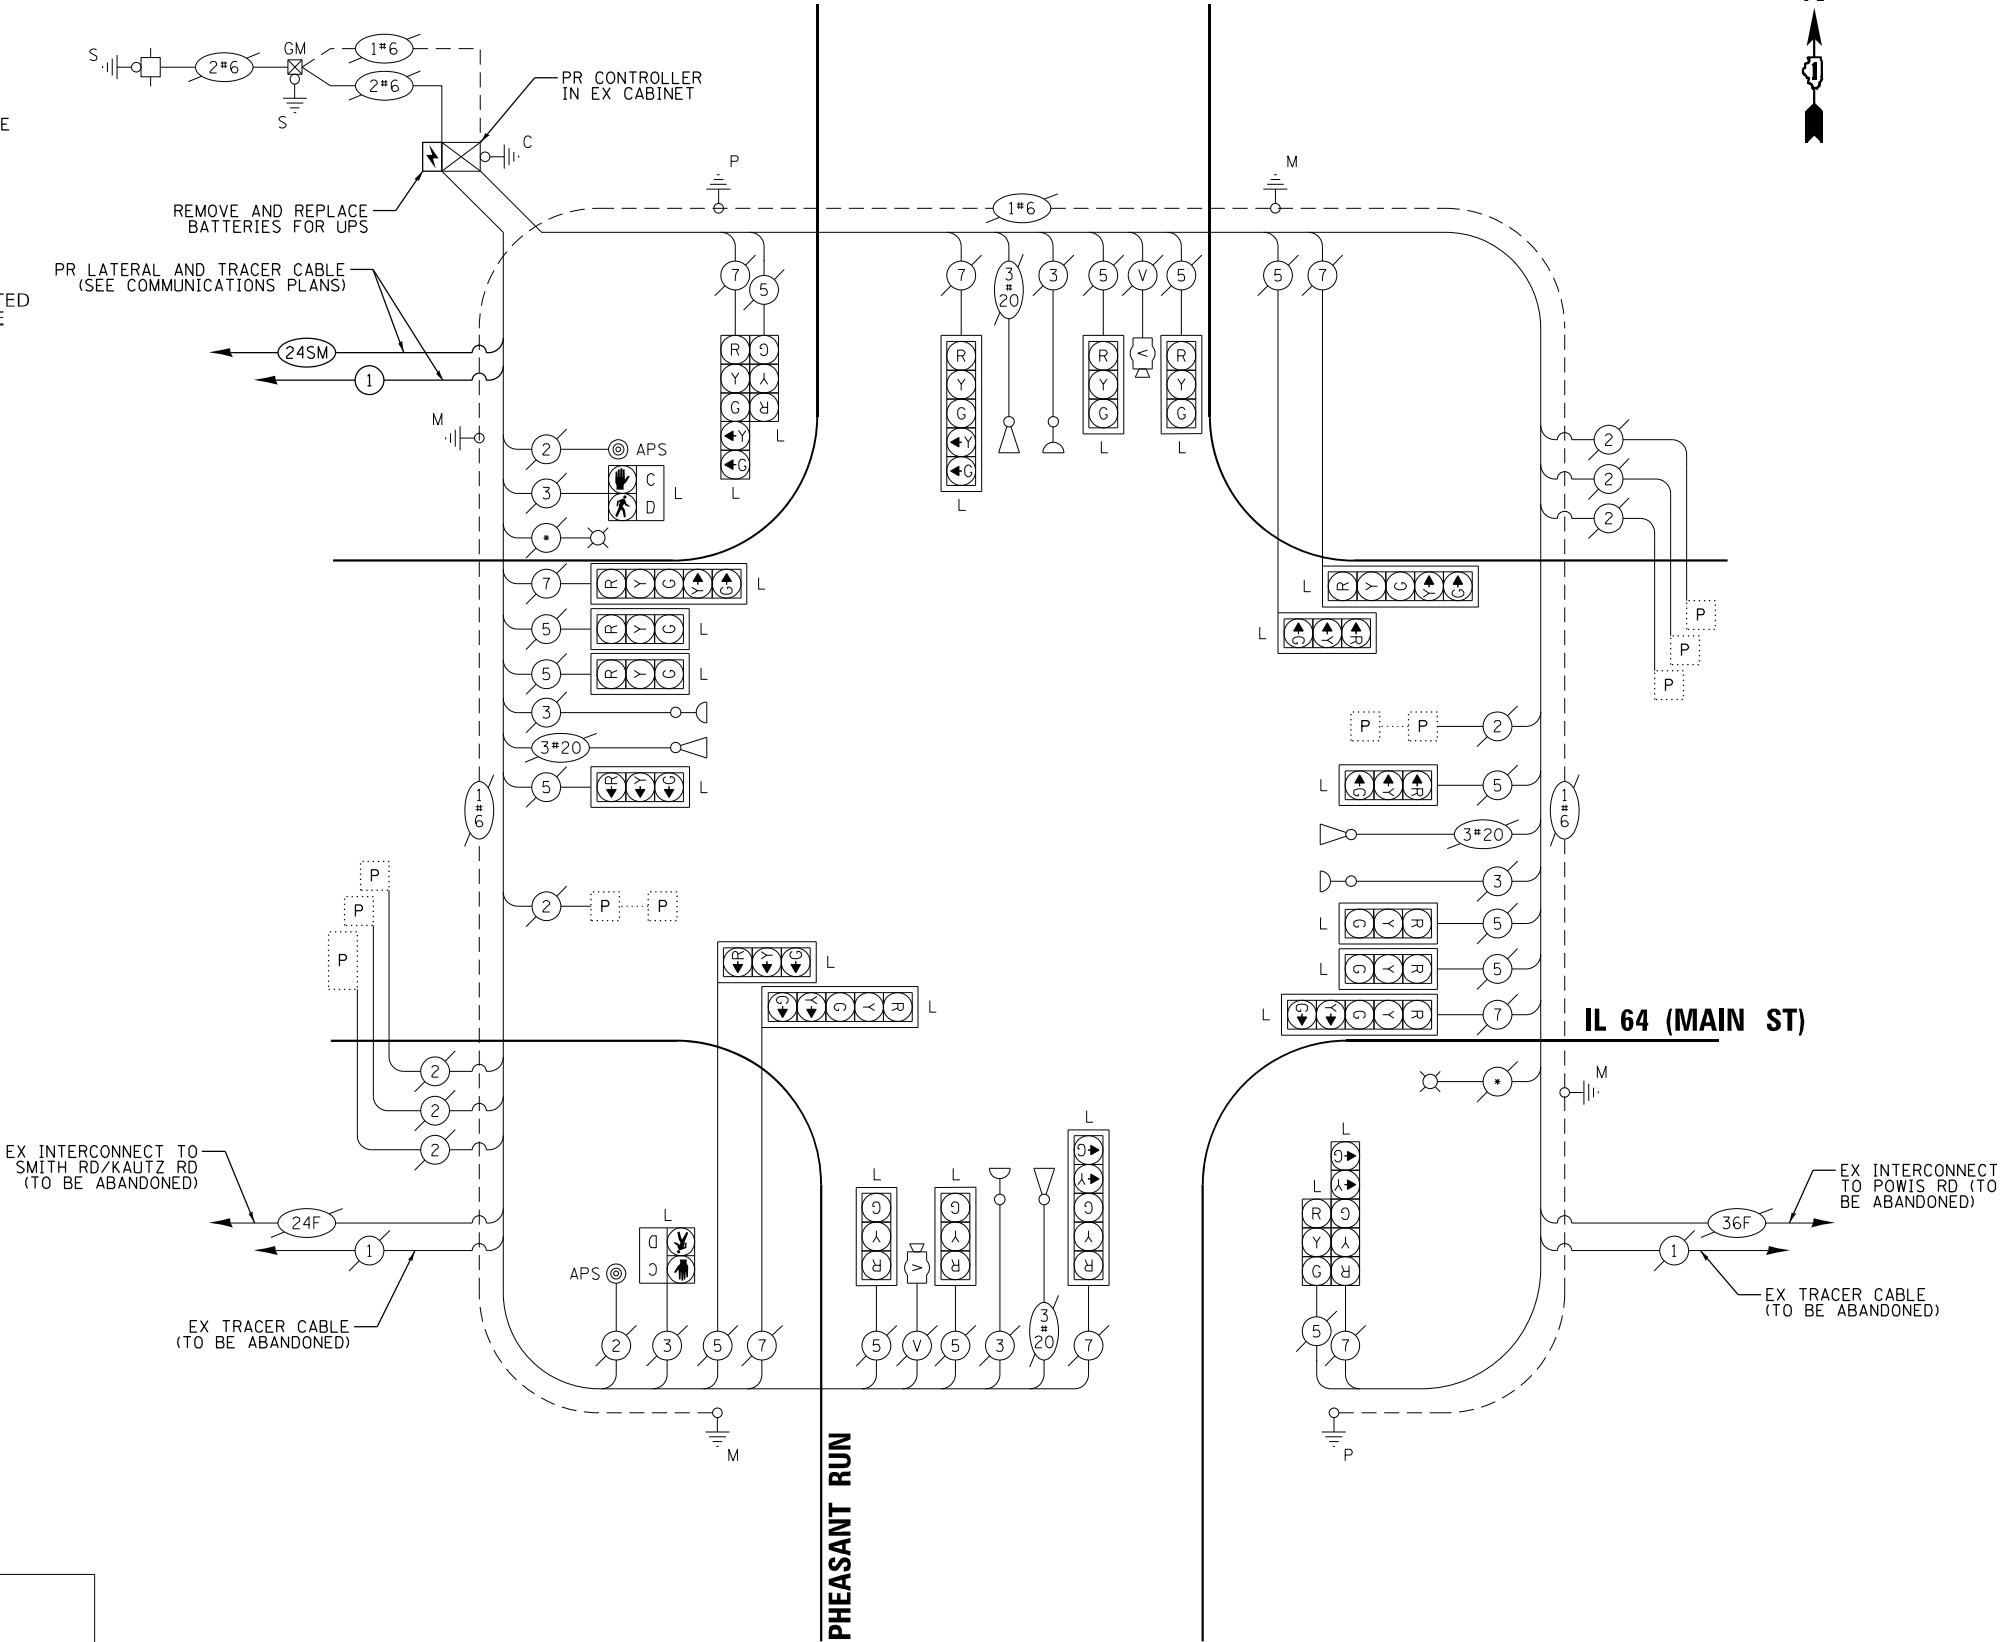

STATE OF ILLINOIS
DEPARTMENT OF TRANSPORTATION

CABLE PLAN, PHASE DESIGNATION DIAGRAM, AND
EMERGENCY VEHICLE PREEMPTION SEQUENCE
IL 64 (MAIN ST) AND PHEASANT RUN

SCALE: N.T.S. SHEET OF SHEETS STA. TO STA.

F.A.P. RTE.	SECTION	COUNTY	TOTAL SHEETS	SHEET NO.
307	2020-263-SUR, SW&TS	DUPAGE	529	114
CONTRACT NO. 62N33				
ILLINOIS FED. AID PROJECT				

TS 9024
IDOT TACTICS
FORMER EAGLE 2M

KimleyHorn

© 2023 KIMLEY-HORN AND ASSOCIATES, INC.
4001 WILHELM D. ROAD, SUITE 600
WARREN, ILL. 60555
PHONE: (847) 455-4555
WWW.KIMLEY-HORN.COM

USER NAME =	DESIGNED -	REVISED -
PLOT SCALE =	DRAWN -	REVISED -
PLOT DATE =	CHECKED -	REVISED -
	DATE -	REVISED -

SIGN PANEL – TYPE 2

ALL DIMENSIONS ARE IN INCHES UNLESS OTHERWISE NOTED



DESIGN SERIES	AREA (SQ. FT)	SIGN PANEL TYPE	SHEETING TYPE	QTY. REQUIRED
D	11.25	2	ZZ	2

SCHEDULE OF QUANTITIES

ITEM DESCRIPTION	UNIT	QUANTITY
SIGN PANEL - TYPE 2	SQ. FT.	22.5
MAINTENANCE OF EXISTING TRAFFIC SIGNAL INSTALLATION	EACH	1
REMOVE EXISTING TRAFFIC SIGNAL EQUIPMENT	EACH	1
LED LAMP MODULE REPLACEMENT	EACH	82
LAYER II (DATALINK) SWITCH	EACH	1
TACTICS LICENSE EXPANSION	EACH	1
FULL-ACTUATED CONTROLLER IN EXISTING CABINET	EACH	1
REMOVE AND REPLACE BATTERIES FOR UNINTERRUPTABLE POWER SUPPLY, EXTENDED	EACH	1
FIBER OPTIC INTERCONNECT CENTER, 48 PORT	EACH	1
ACCESSIBLE PEDESTRIAN SIGNALS	EACH	2
LED SIGNAL FACE, LENS COVER	EACH	22
LED PEDESTRIAN SIGNAL MODULE REPLACEMENT	EACH	6
TERMINATE FIBER IN CABINET	EACH	12

TS 9024
IDOT TACTICS
FORMER EAGLE 2M

Model: Default
File: Name: p:\sub-pw-bentley.com\k-h-pw-d\1\Documents\01 Active Projects\MMW-CL-S-160950\00 - IL 64\Phase 01\2 Design\CAD\Plan Sheets\Sign\11West Corridor Sign\BID\081714\rt-12_K4A.dgn

© 2023 KIMLEY-HORN AND ASSOCIATES, INC.
4001 HWY 10, ROAD SUITE 600
WARREN, IL 6. 05055
PHONE: 815.447.4555
WWW.KIMLEY-HORN.COM

USER NAME =	DESIGNED -	REVISED -
	DRAWN -	REVISED -
PLOT SCALE =	CHECKED -	REVISED -
PLOT DATE =	DATE -	REVISED -

STATE OF ILLINOIS
DEPARTMENT OF TRANSPORTATION



MAST ARM MOUNTED STREET NAME SIGNS AND
SCHEDULE OF QUANTITIES
IL 64 (MAIN ST) AND PHEASANT RUN

SCALE: N.T.S.

SHEET OF SHEETS

STA. TO STA.

F.A.P. RTE.	SECTION	COUNTY	TOTAL SHEETS	SHEET NO.
307	2020-263-SUR,SW&TS	DUPAGE	529	115
CONTRACT NO. 62N33				
		ILLINOIS	FED. AID PROJECT	

 
 


Kimley»Horn
© 2023 KIMLEY-HORN AND ASSOCIATES, INC.
4201 WILMFIELD ROAD, SUITE 600
WARRENVILLE, IL 60555
PHONE: 830-487-6550
WWW.KIMLEY-HORN.COM


STATE OF ILLINOIS
DEPARTMENT OF TRANSPORTATION

SCALE: 1" = 20'	SHEET	OF	SHEETS	STA.	TO STA.
-----------------	-------	----	--------	------	---------

F.A.P. RTE.	SECTION	COUNTY	TOTAL SHEETS	SHEET NO.
307	2020-263-SUR, SW&TS	DUPAGE	529	117
		CONTRACT NO. 62N33		
ILLINOIS		FED. AID PROJECT		

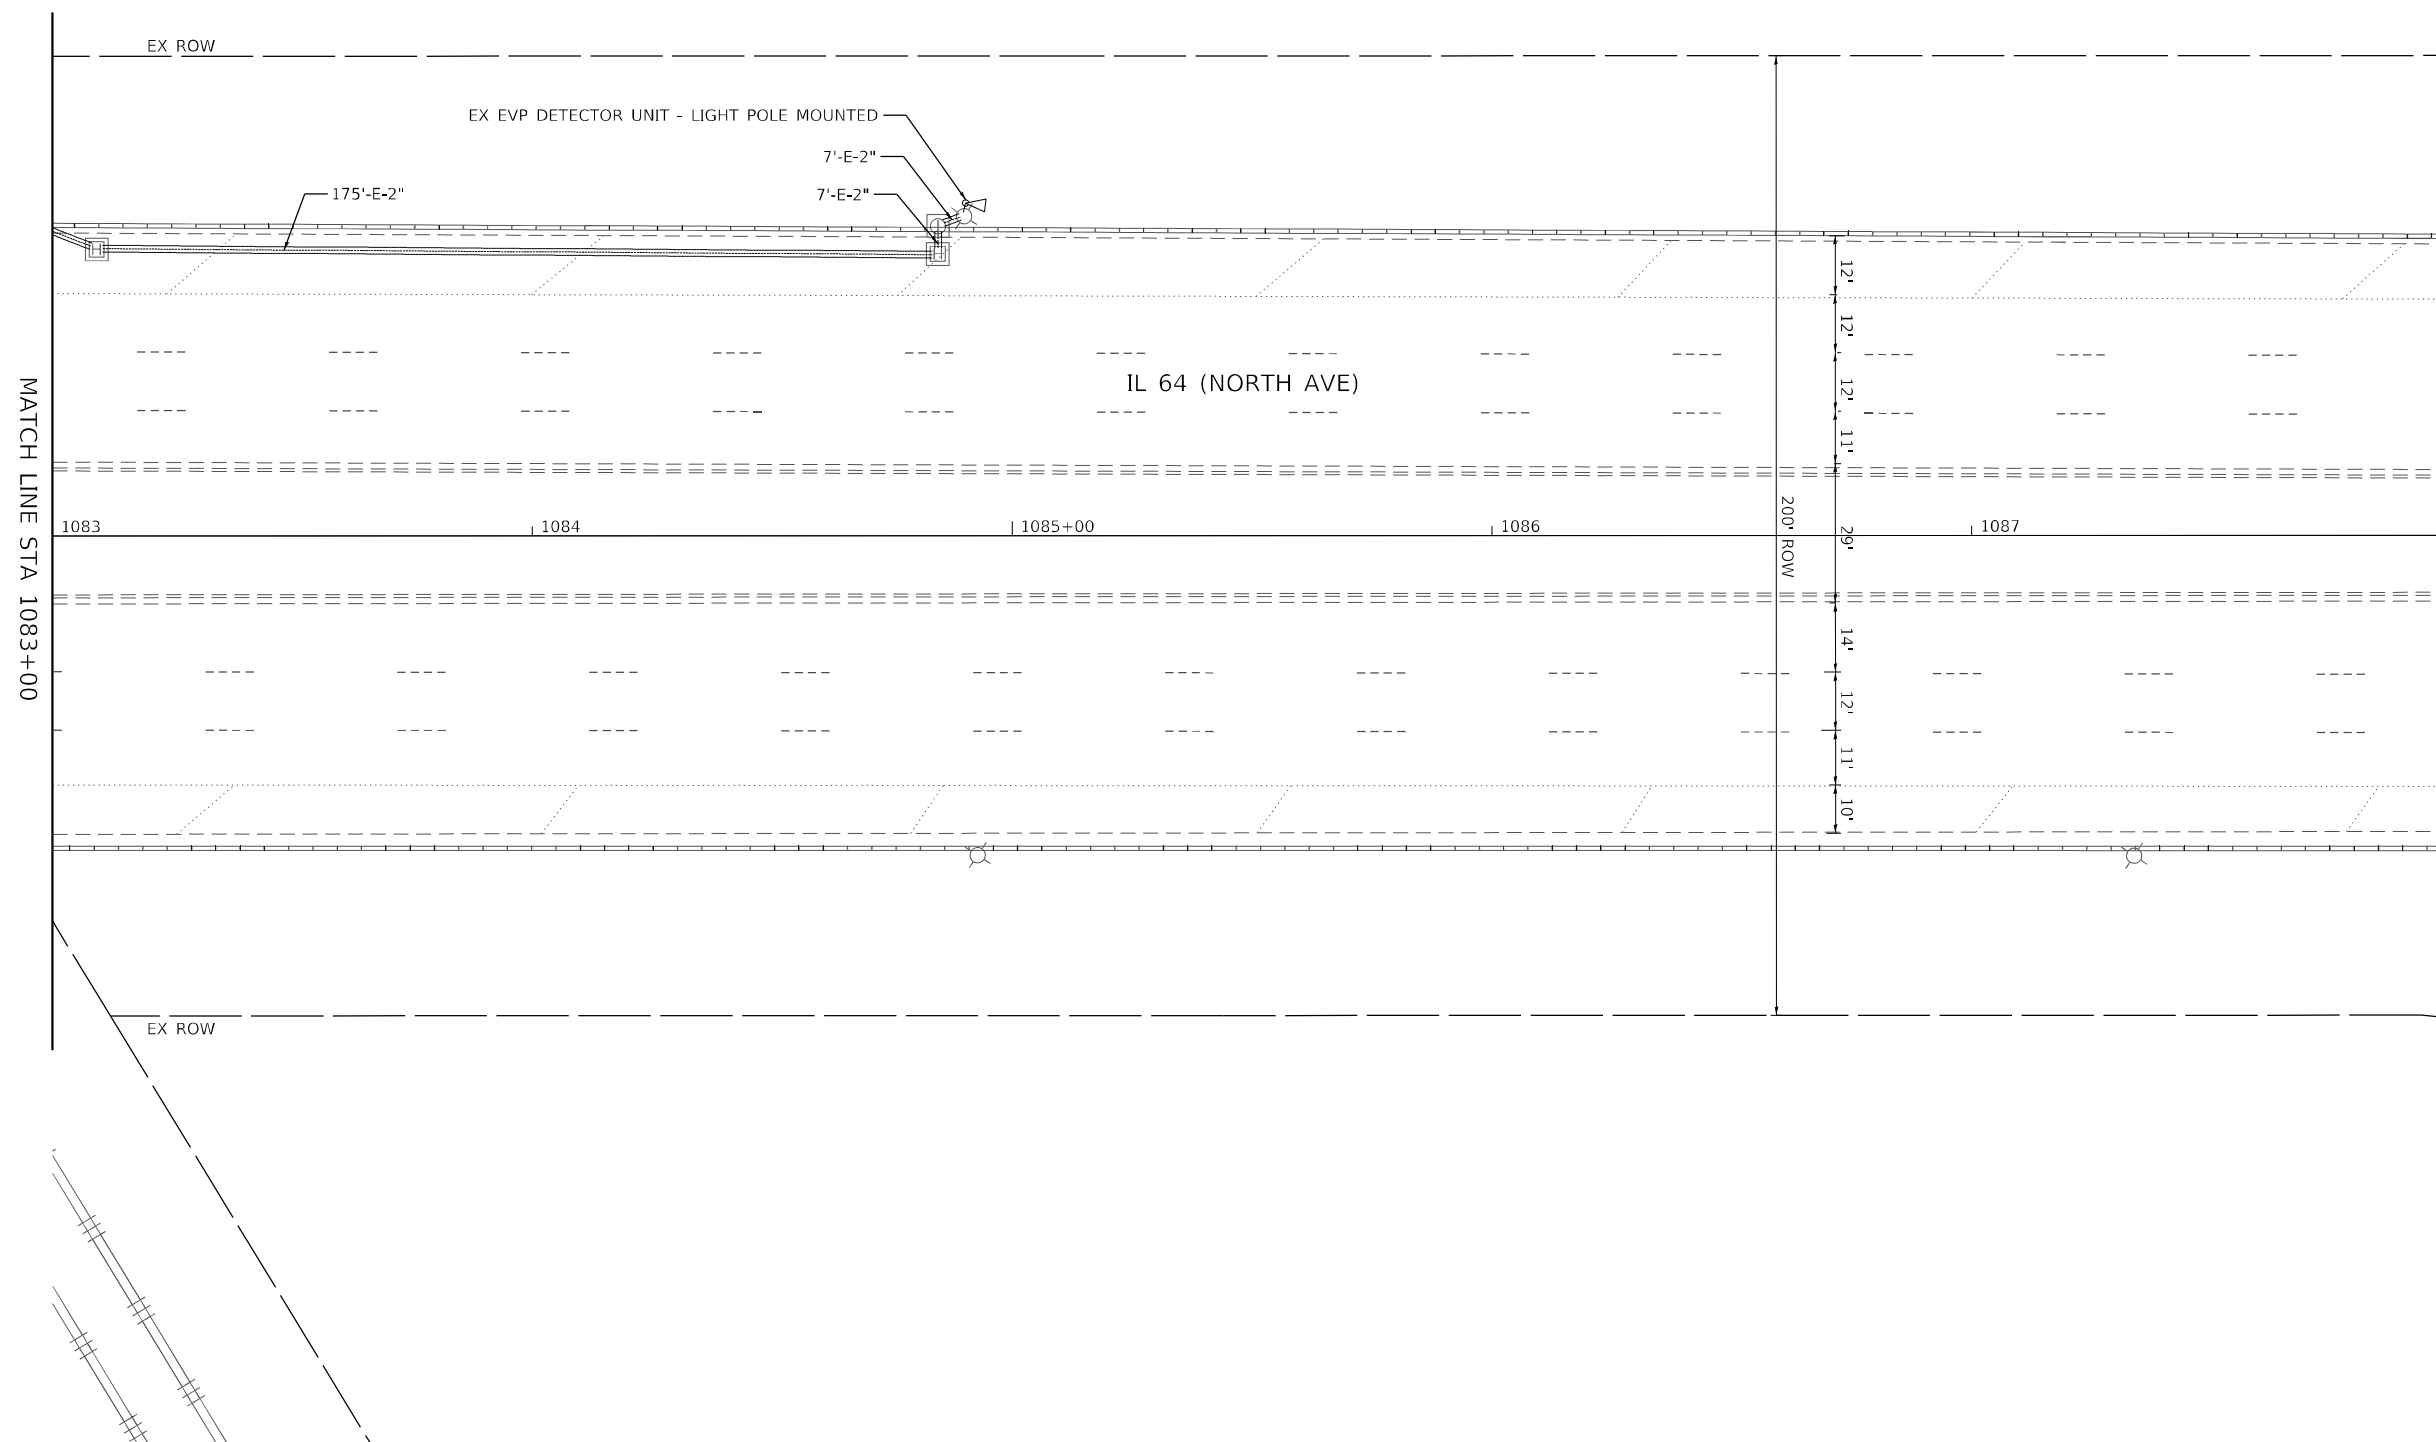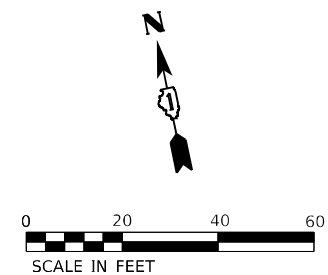

TS 12070
IDOT TACTICS
FORMER EAGLE 2M

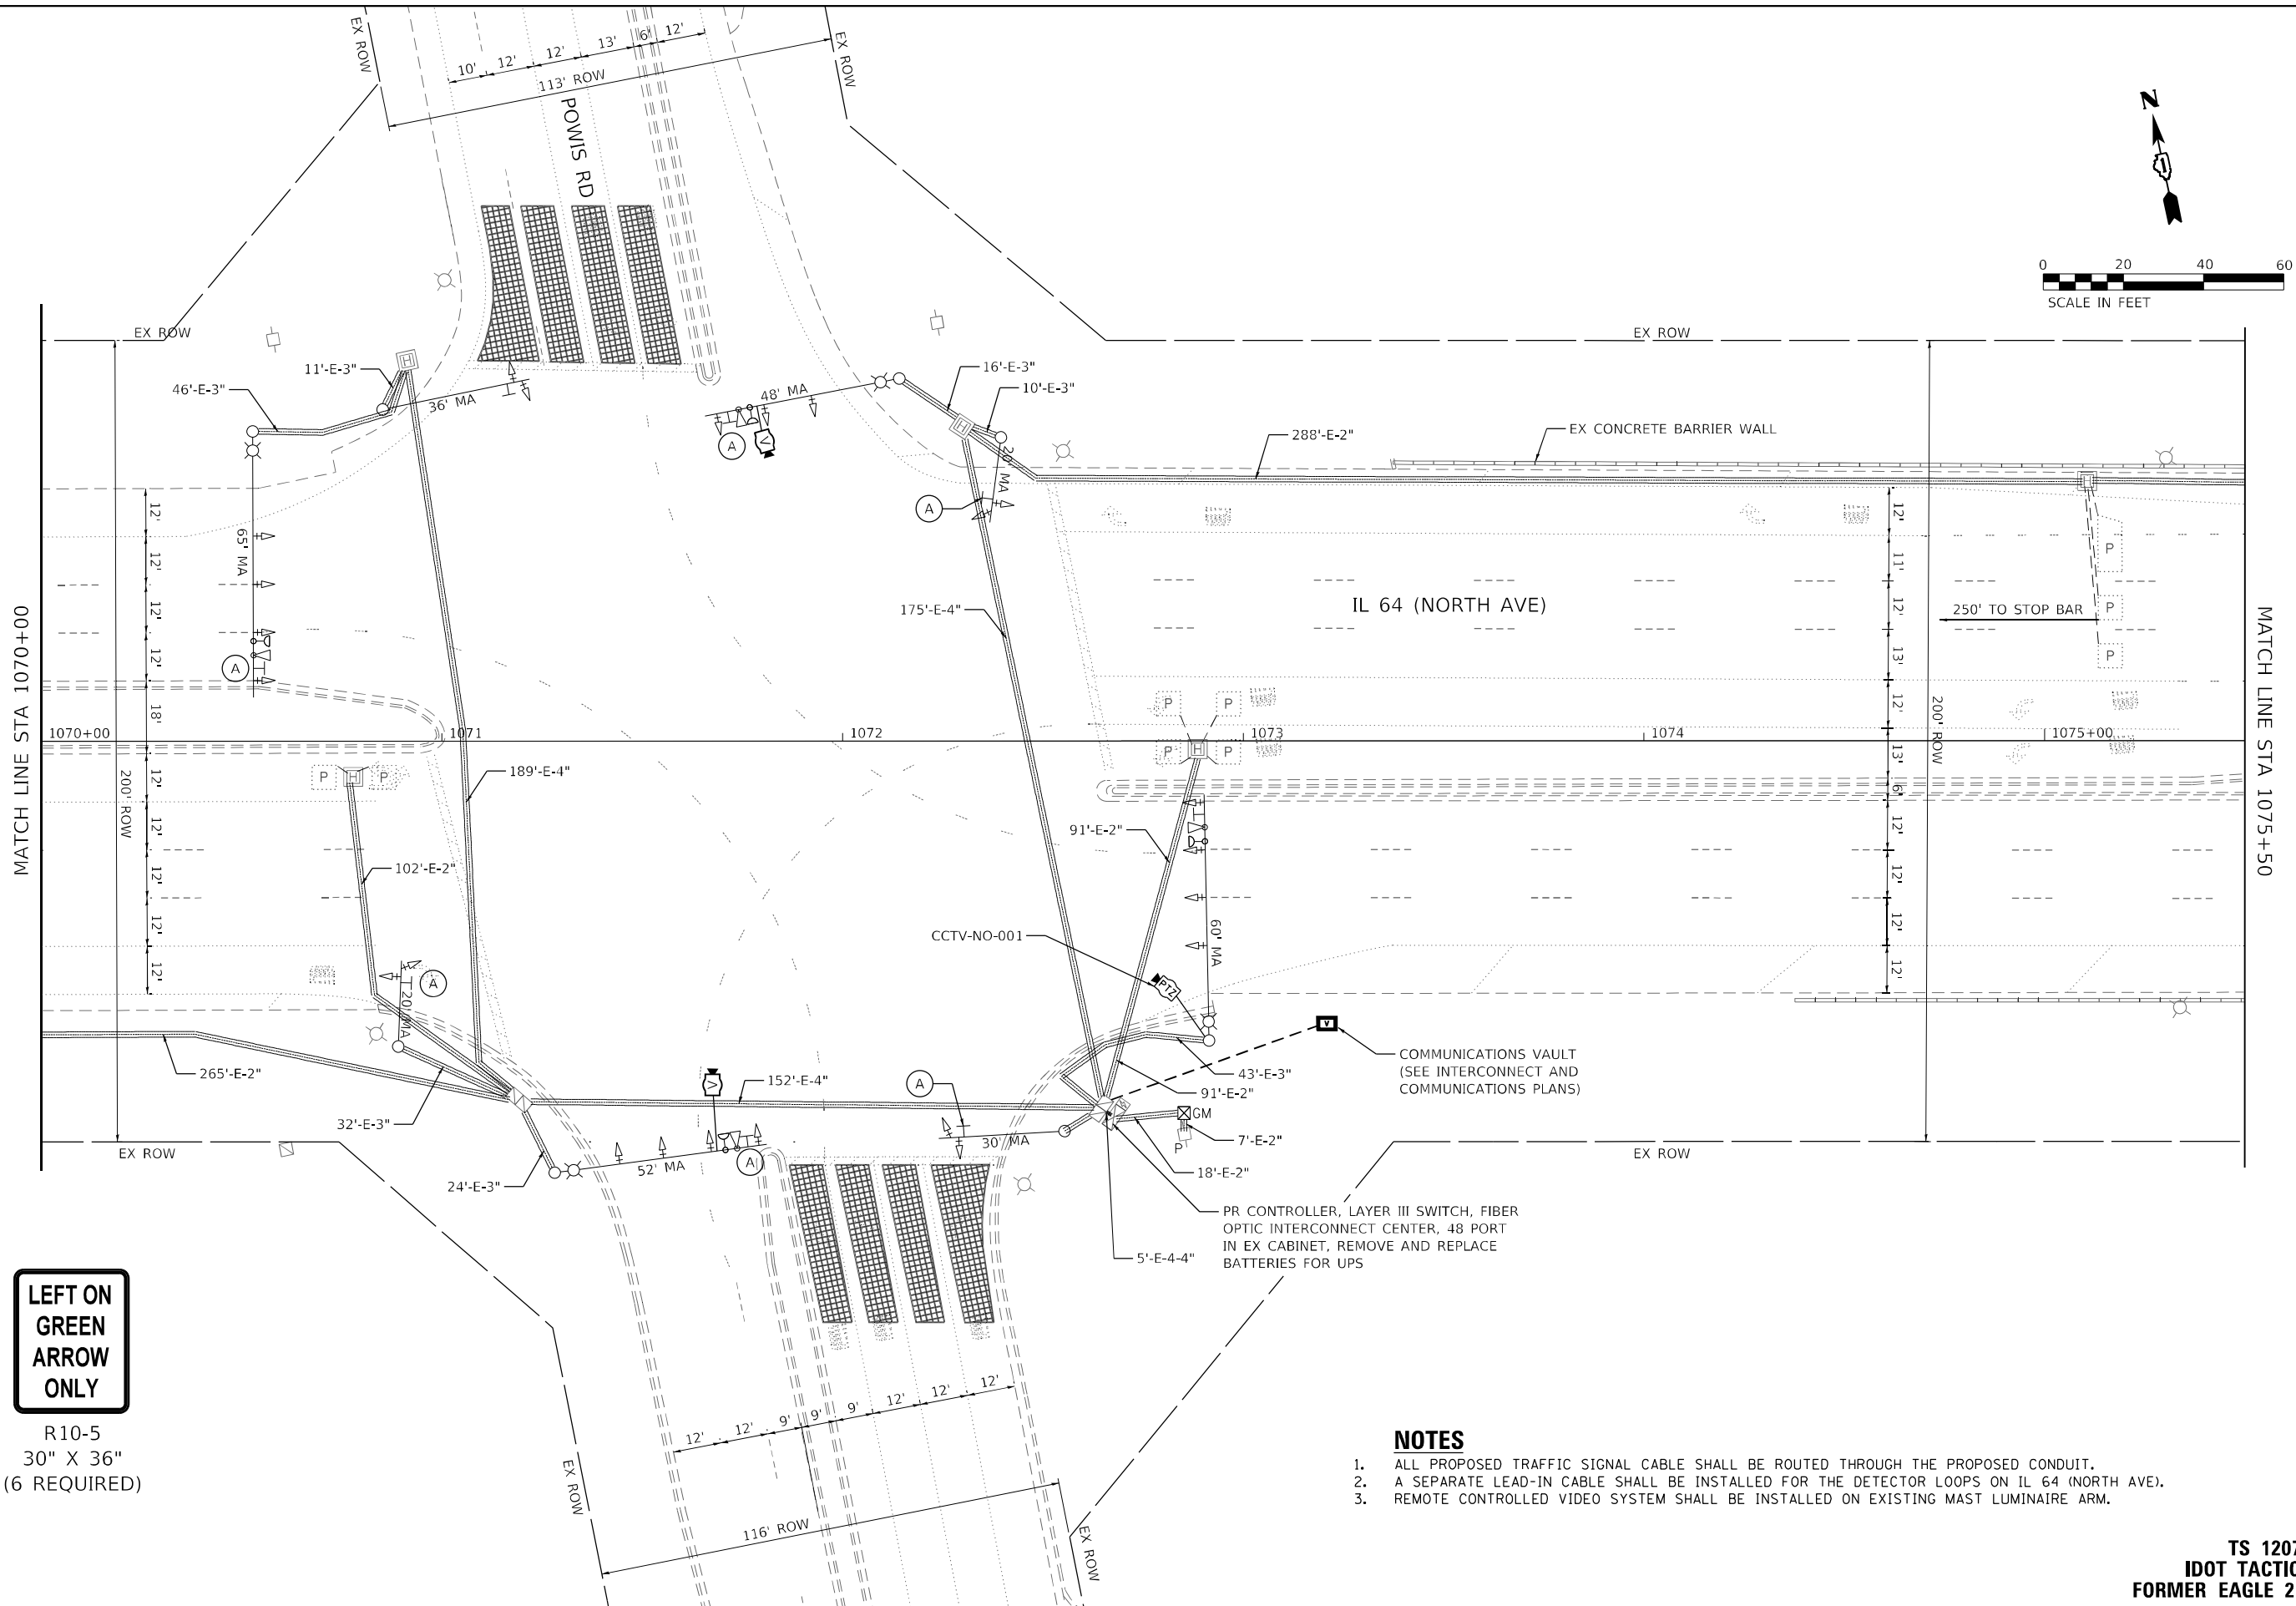

**LEFT ON GREEN
ARROW ONLY**

R10-5
30" X 36"
(6 REQUIRED)

- NOTES**
1. ALL PROPOSED TRAFFIC SIGNAL CABLE SHALL BE ROUTED THROUGH THE PROPOSED CONDUIT.
 2. A SEPARATE LEAD-IN CABLE SHALL BE INSTALLED FOR THE DETECTOR LOOPS ON IL 64 (NORTH AVE).
 3. REMOTE CONTROLLED VIDEO SYSTEM SHALL BE INSTALLED ON EXISTING MAST LUMINAIRE ARM.

**TS 12070
IDOT TACTICS
FORMER EAGLE 2M**

Kimley»Horn

© 2021 KIMLEY-HORN AND ASSOCIATES, INC.
4001 WILSON ROAD, SUITE 600
WARREN, IL 60555
PHONE: (847) 455-4555
WWW.KIMLEY-HORN.COM

USER NAME =	DESIGNED -	REVISED -
DRAWN -	REVISOR -	
PLOT SCALE =	CHECKED -	REVISED -
PLOT DATE =	DATE -	REVISED -

**STATE OF ILLINOIS
DEPARTMENT OF TRANSPORTATION**

**TRAFFIC SIGNAL MODERNIZATION PLAN
IL 64 (NORTH AVE) AND POWIS RD**

SCALE: 1" = 20' SHEET OF SHEETS STA. TO STA.

F.A.P. RTE.	SECTION	COUNTY	TOTAL SHEETS	SHEET NO.
307	2020-263-SUR, SW&TS	DUPAGE	529	120
CONTRACT NO. 62N33				
ILLINOIS FED. AID PROJECT				

MODEL: Default
FILE: \\naulpc-prod\h-pw\bartley.com\h-pw-d\1\Documents\01 Active Projects\IMW\CHS-168950\00 - IL 64\Phase 1\12 Design\CAD\Plan Streets\Signal\West Corridor Signal\01081714\14-ts-18_KIM.dgn






USER NAME =	DESIGNED -	REVISED -
	DRAWN -	REVISED -
PLOT SCALE =	CHECKED -	REVISED -
PLOT DATE =	DATE -	REVISED -



STATE OF ILLINOIS
DEPARTMENT OF TRANSPORTATION

TRAFFIC SIGNAL MODERNIZATION PLAN			
IL 64 (NORTH AVE) AND POWIS RD			
SCALE: 1" = 20'	SHEET	OF	SHEETS
	STA.	TO	STA.

F.A.P. RTE.	SECTION	COUNTY	TOTAL SHEETS	SHEET NO.
307	2020-263-SUR, SW&TS	DUPAGE	529	121
CONTRACT NO. 62N33				
ILLINOIS		FED. AID PROJECT		



TS 12070
IDOT TACTICS
FORMER EAGLE 2M

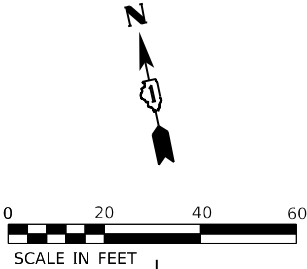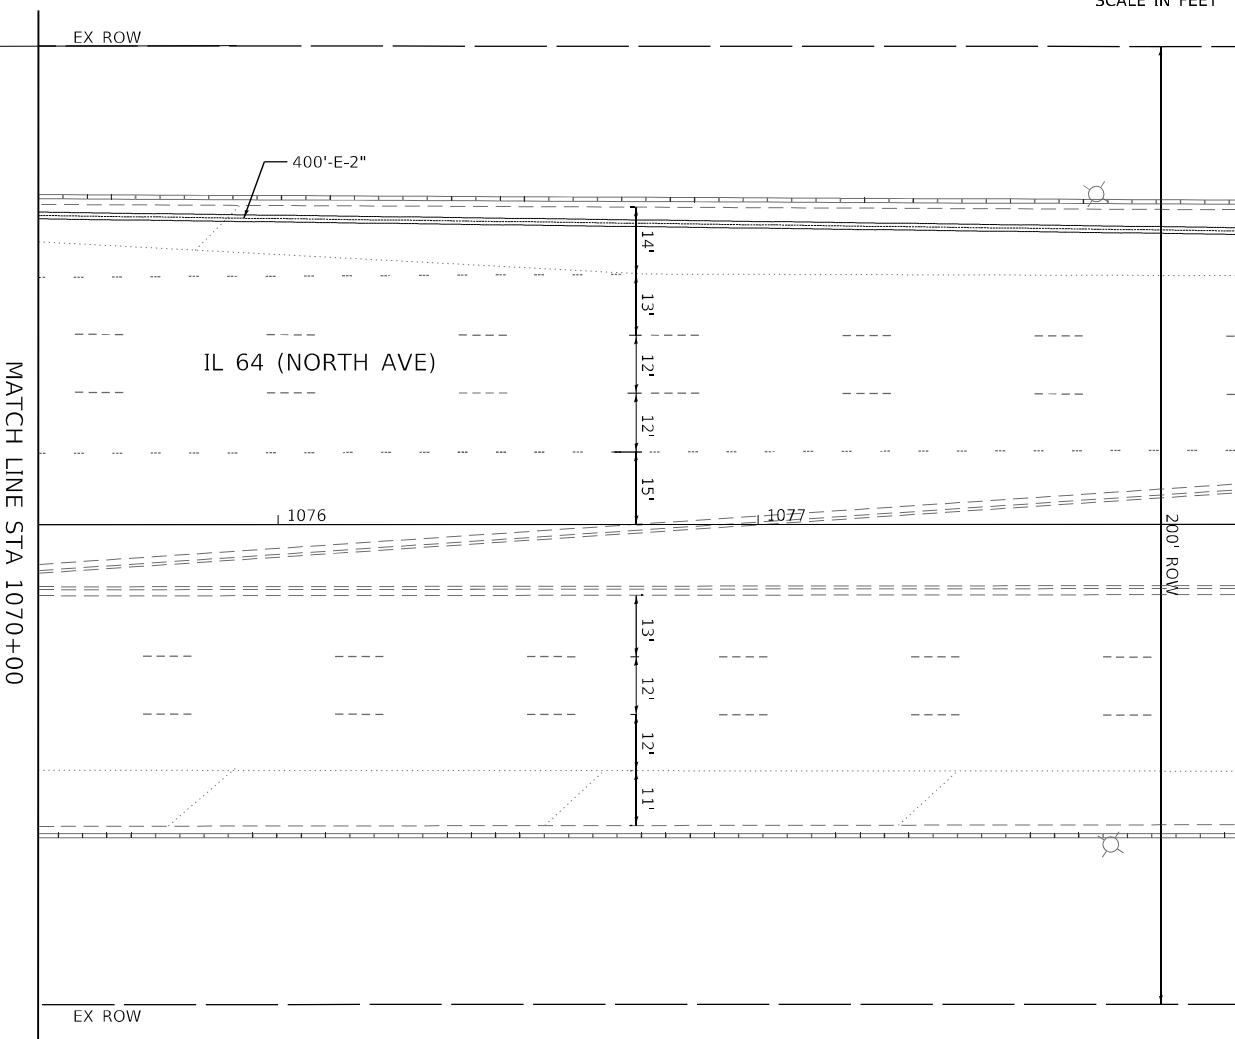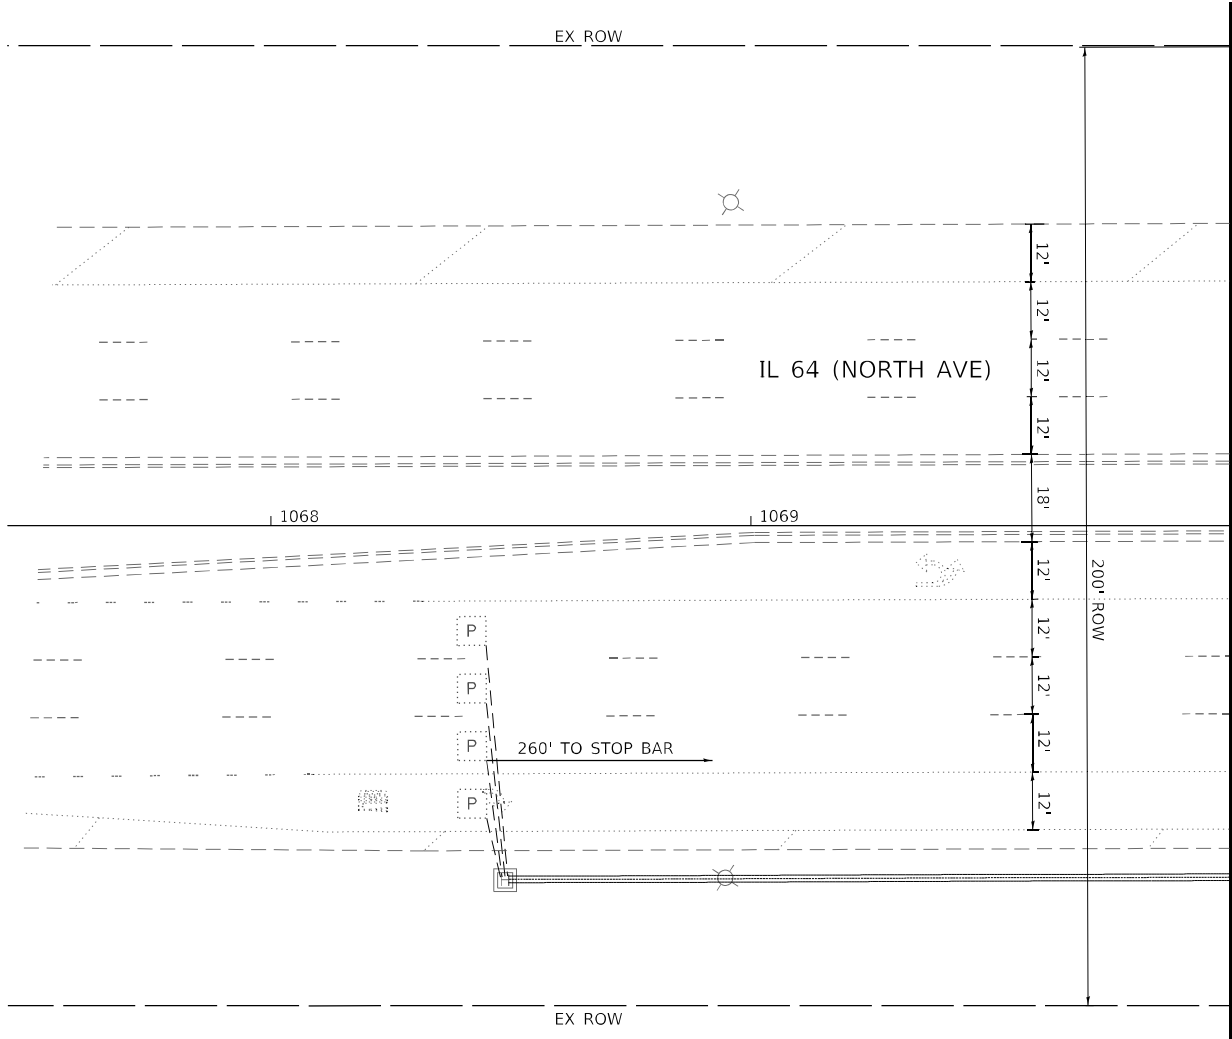

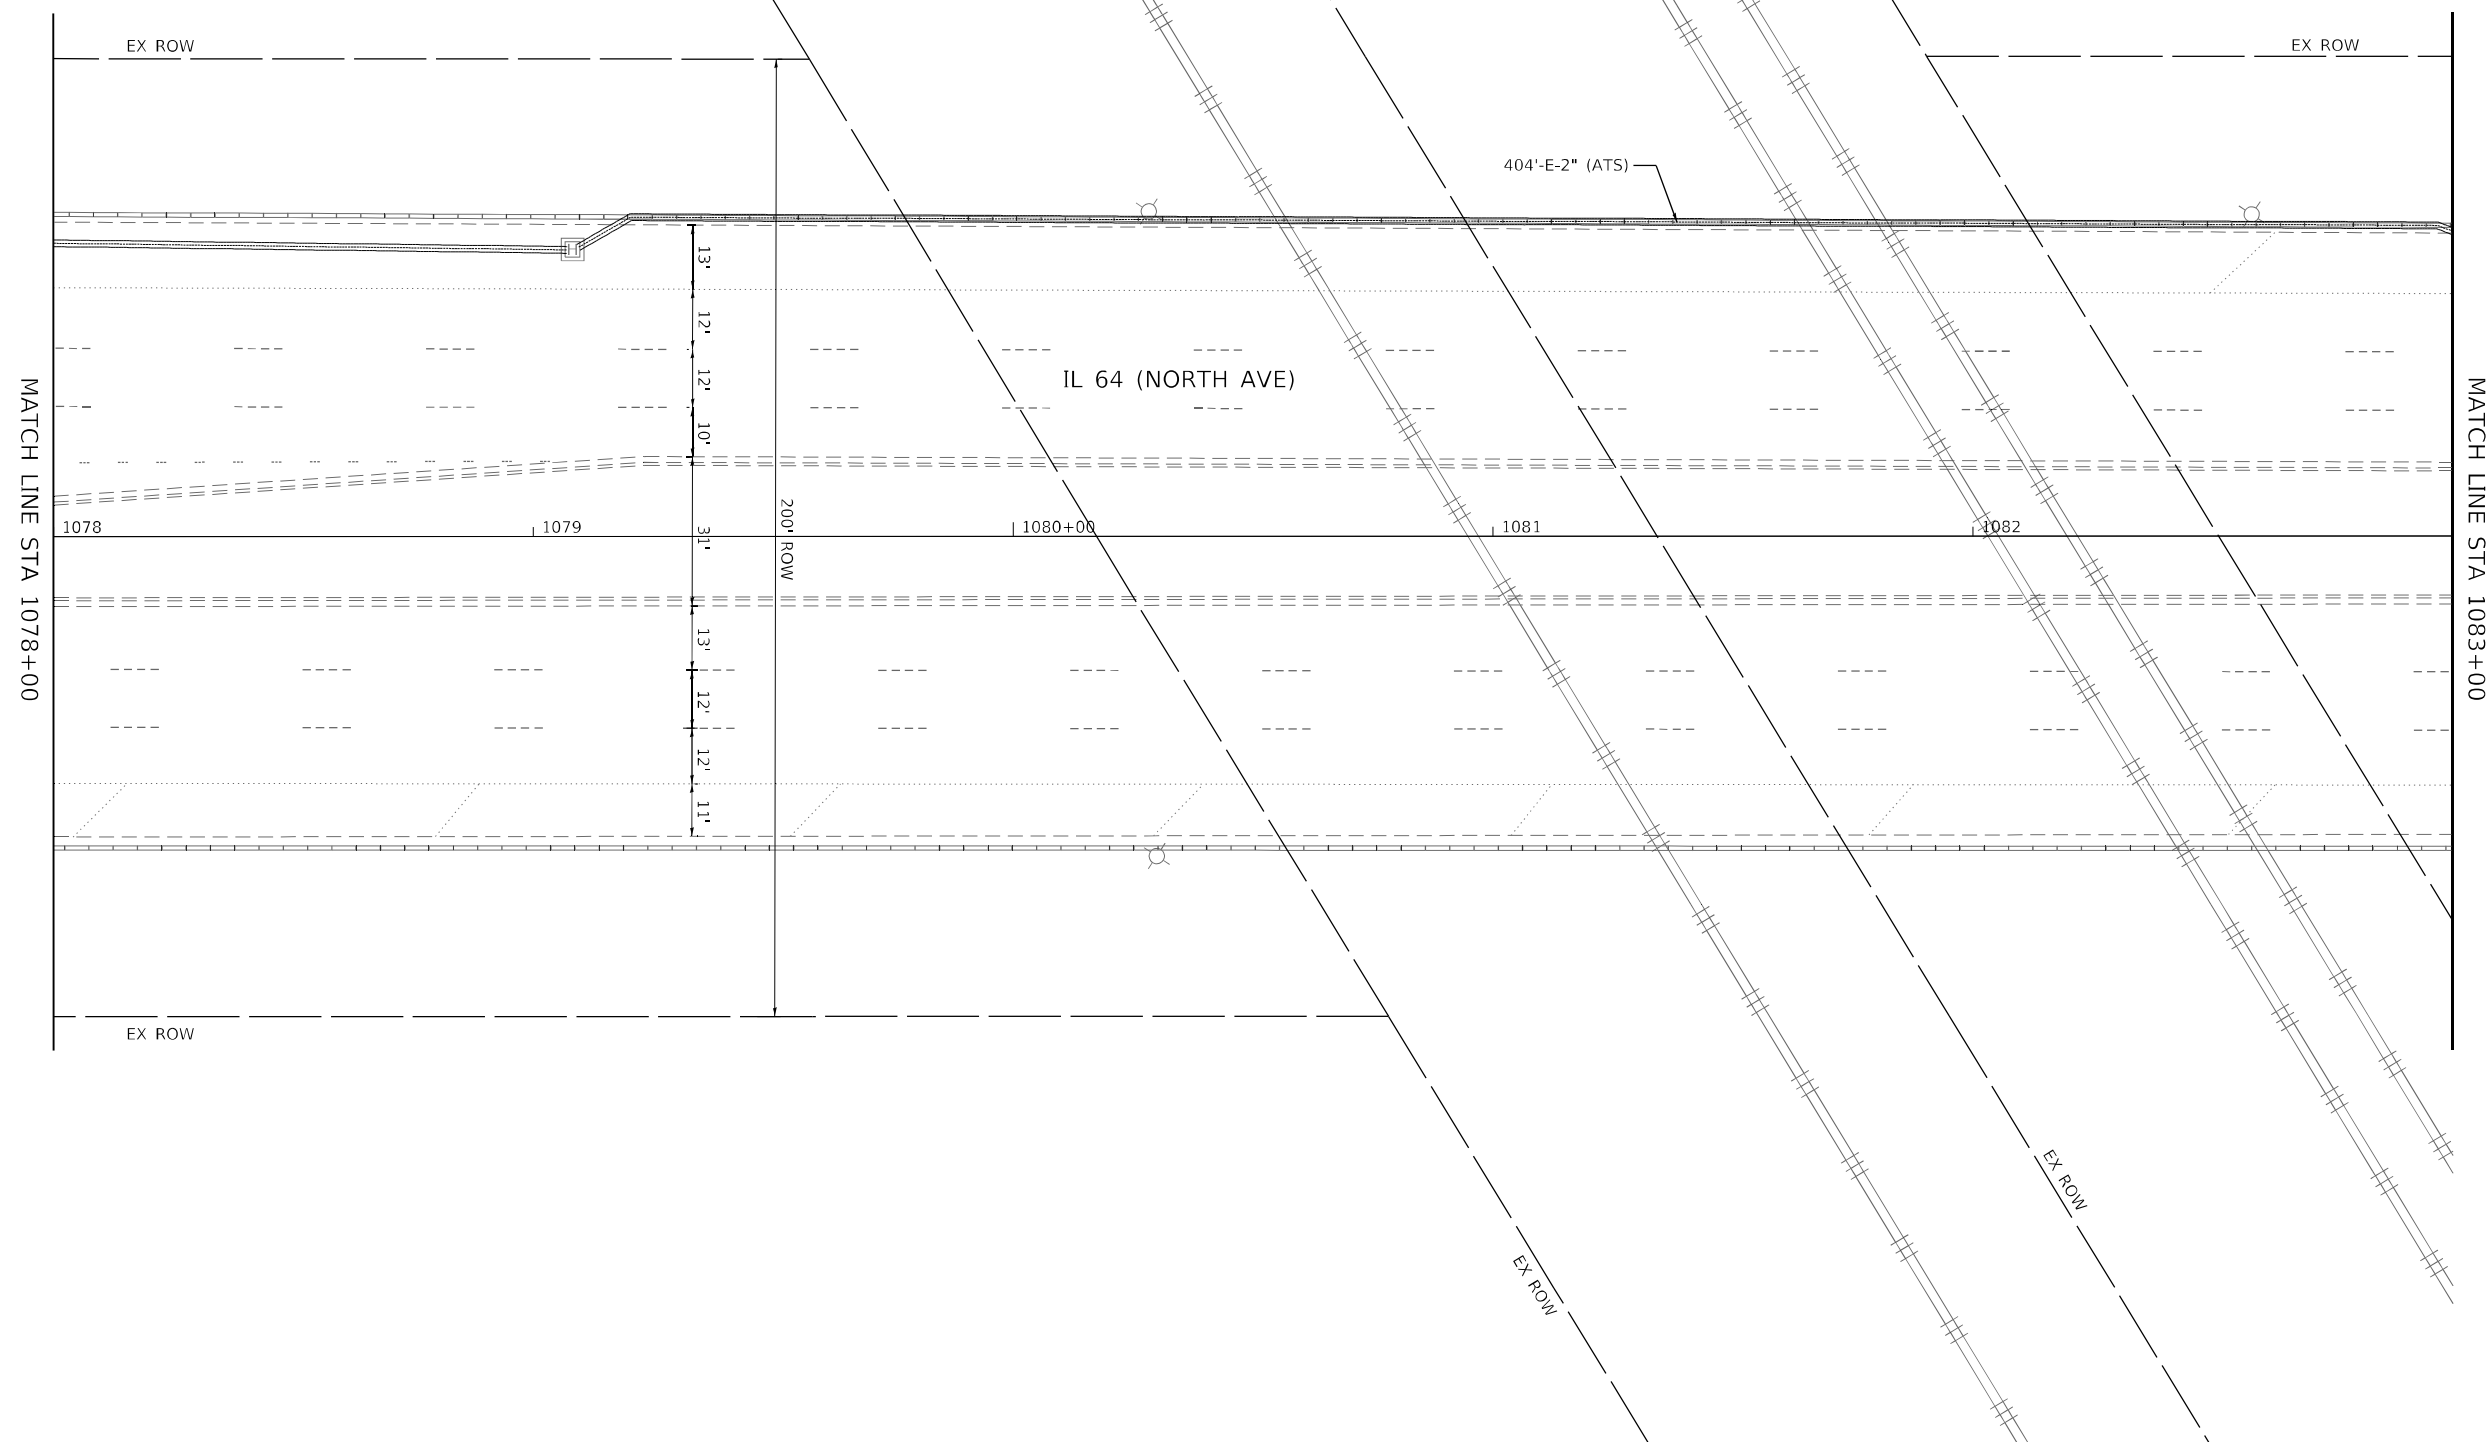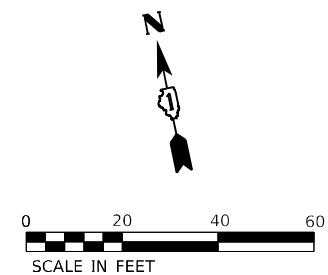

**TS 12070
IDOT TACTICS
FORMER EAGLE 2M**

 © 2022 KIMLEY-HORN AND ASSOCIATES, INC. 4001 NORTON D. ROAD, SUITE 400 VANDERBILT, IL 61555 PHONE: 630-440-6050 WWW.KIMLEY-HORN.COM	USER NAME =	DESIGNED -	REVISED -	STATE OF ILLINOIS DEPARTMENT OF TRANSPORTATION	TRAFFIC SIGNAL MODERNIZATION PLAN IL 64 (NORTH AVE) AND POWIS RD					F.A.P. RTE.	SECTION	COUNTY	TOTAL SHEETS	SHEET NO.
		DRAWN -	REVISED -		307	2020-263-SUR, SW&TS	DUPAGE	529	122					
	PLOT SCALE =	CHECKED -	REVISED -		CONTRACT NO. 62N33									
	PLOT DATE =	DATE -	REVISED -		SCALE: 1" = 20'	SHEET	OF	SHEETS	STA.	TO STA.	ILLINOIS	FED. AID PROJECT		

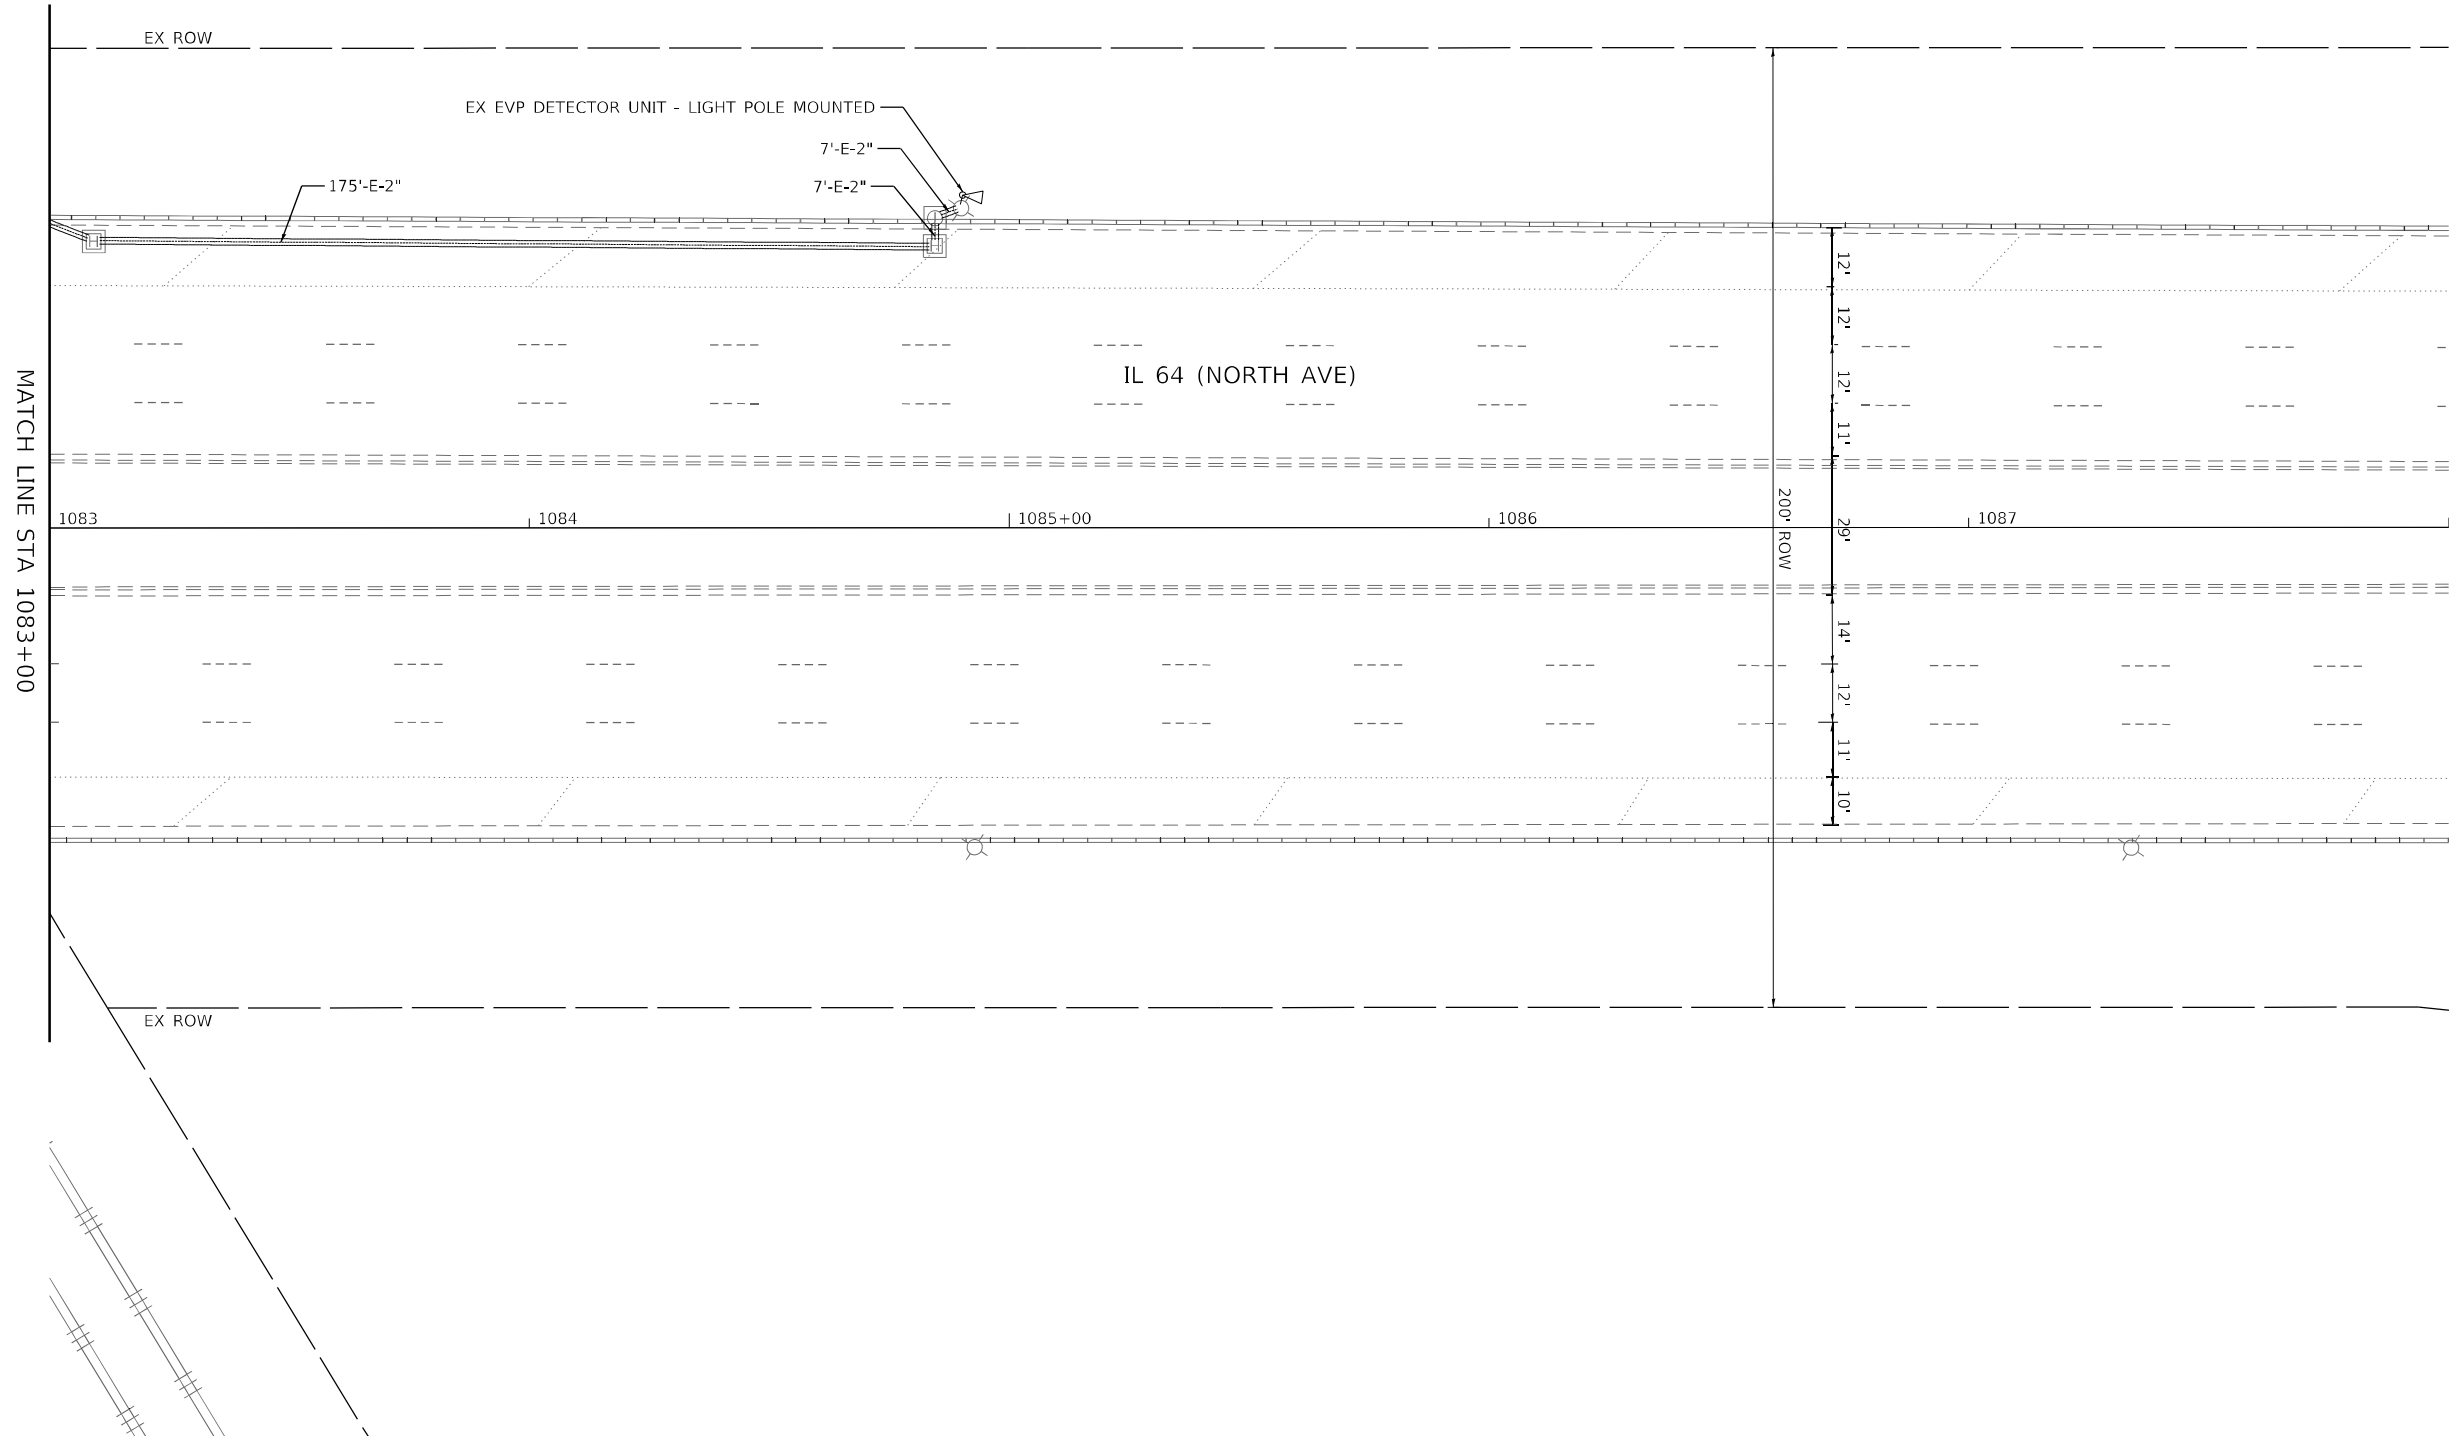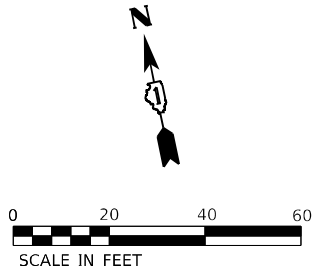

MODEL: Default
FILE NAME: p:\sub-pw\bartley.com\ts-62n33\11\Documents\01 Active Projects\MW\CHS-168950\00 - IL 64\Phase II\2 Design\CAD\Plan Sheets\Signal\West Corridor Signal\108171-108172-20_KIM.dgn



USER NAME =	DESIGNED -	REVISED -
	DRAWN -	REVISED -
	CHECKED -	REVISED -
	DATE -	REVISED -


STATE OF ILLINOIS
DEPARTMENT OF TRANSPORTATION

TRAFFIC SIGNAL MODERNIZATION PLAN			
IL 64 (NORTH AVE) AND POWIS RD			
SCALE: 1" = 20'	SHEET	OF	SHEETS
STA.		TO STA.	

F.A.P. RTE.	SECTION	COUNTY	TOTAL SHEETS	SHEET NO.
307	2020-263-SUR, SW&TS	DUPAGE	529	123
CONTRACT NO. 62N33				
ILLINOIS		FED. AID PROJECT		

TS 12070
IDOT TACTICS
FORMER EAGLE 2M

EXISTING AND PROPOSED
CONTROLLER SEQUENCE

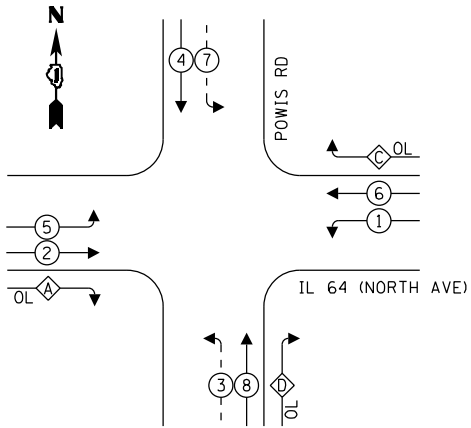


LEGEND:

- ← (⊛) — PROTECTED PHASE
- ← - (⊛) - — PROTECTED/PERMITTED PHASE
- ← (⊛) → — PEDESTRIAN PHASE
- ⊛ OL — OVERLAP

OVERLAP LETTER	=	PERMISSIVE PHASE	+	PROTECTED PHASE
A	=	2	+	3
C	=	6	+	7
D	=	8	+	1

EXISTING AND PROPOSED EMERGENCY
VEHICLE PREEMPTION SEQUENCE

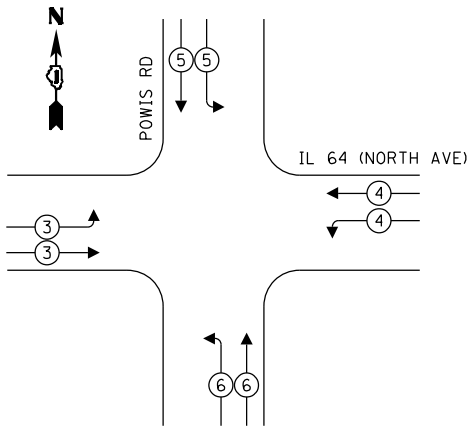

TRAFFIC SIGNAL
ELECTRICAL SERVICE REQUIREMENTS

TYPE	QUANTITY	UNIT WATTAGE	TOTAL WATTAGE
SIGNAL HEAD 1 OR 3-SECTION	17	11	187
4-SECTION	-	14	-
5-SECTION	6	13	78
PROGRAMMABLE 3-SECTION	-	22	-
4-SECTION	-	32	-
5-SECTION	-	28	-
PEDESTRIAN SIGNAL	-	15	-
CONTROLLER	1	150	150
MASTER CONTROLLER	-	100	-
UPS	1	25	25
DETECTION VIDEO	2	20	40
BLANK-OUT SIGN	-	25	-
NETWORK SWITCH LAYER II OR III	1	35	35
CELLULAR MODEM	-	15	-
PTZ	1	75	75
TOTAL UPS SIZING		590	
UPS CHARGING	1	225	225
BATTERY HEATER MAT	1	180	180
CABINET HEATER	1	200	200
FLASHER	-	15	-
LED STREET NAME SIGN	-	120	-
LUMINAIRE	-	240	-
TOTAL SERVICE WIRE SIZING		1195	


ENERGY COSTS TO:
CITY OF WEST CHICAGO
475 MAIN ST
WEST CHICAGO, IL 60185

ENERGY SUPPLY: COMPANY: COMED
PHONE: (866) 639-3532
ACCOUNT NUMBER: 73470-49055

LEGEND:

- L = LED LAMP MODULE REPLACEMENT
- * = ROADWAY LIGHTING CABLE

CABLE PLAN
(NOT TO SCALE)

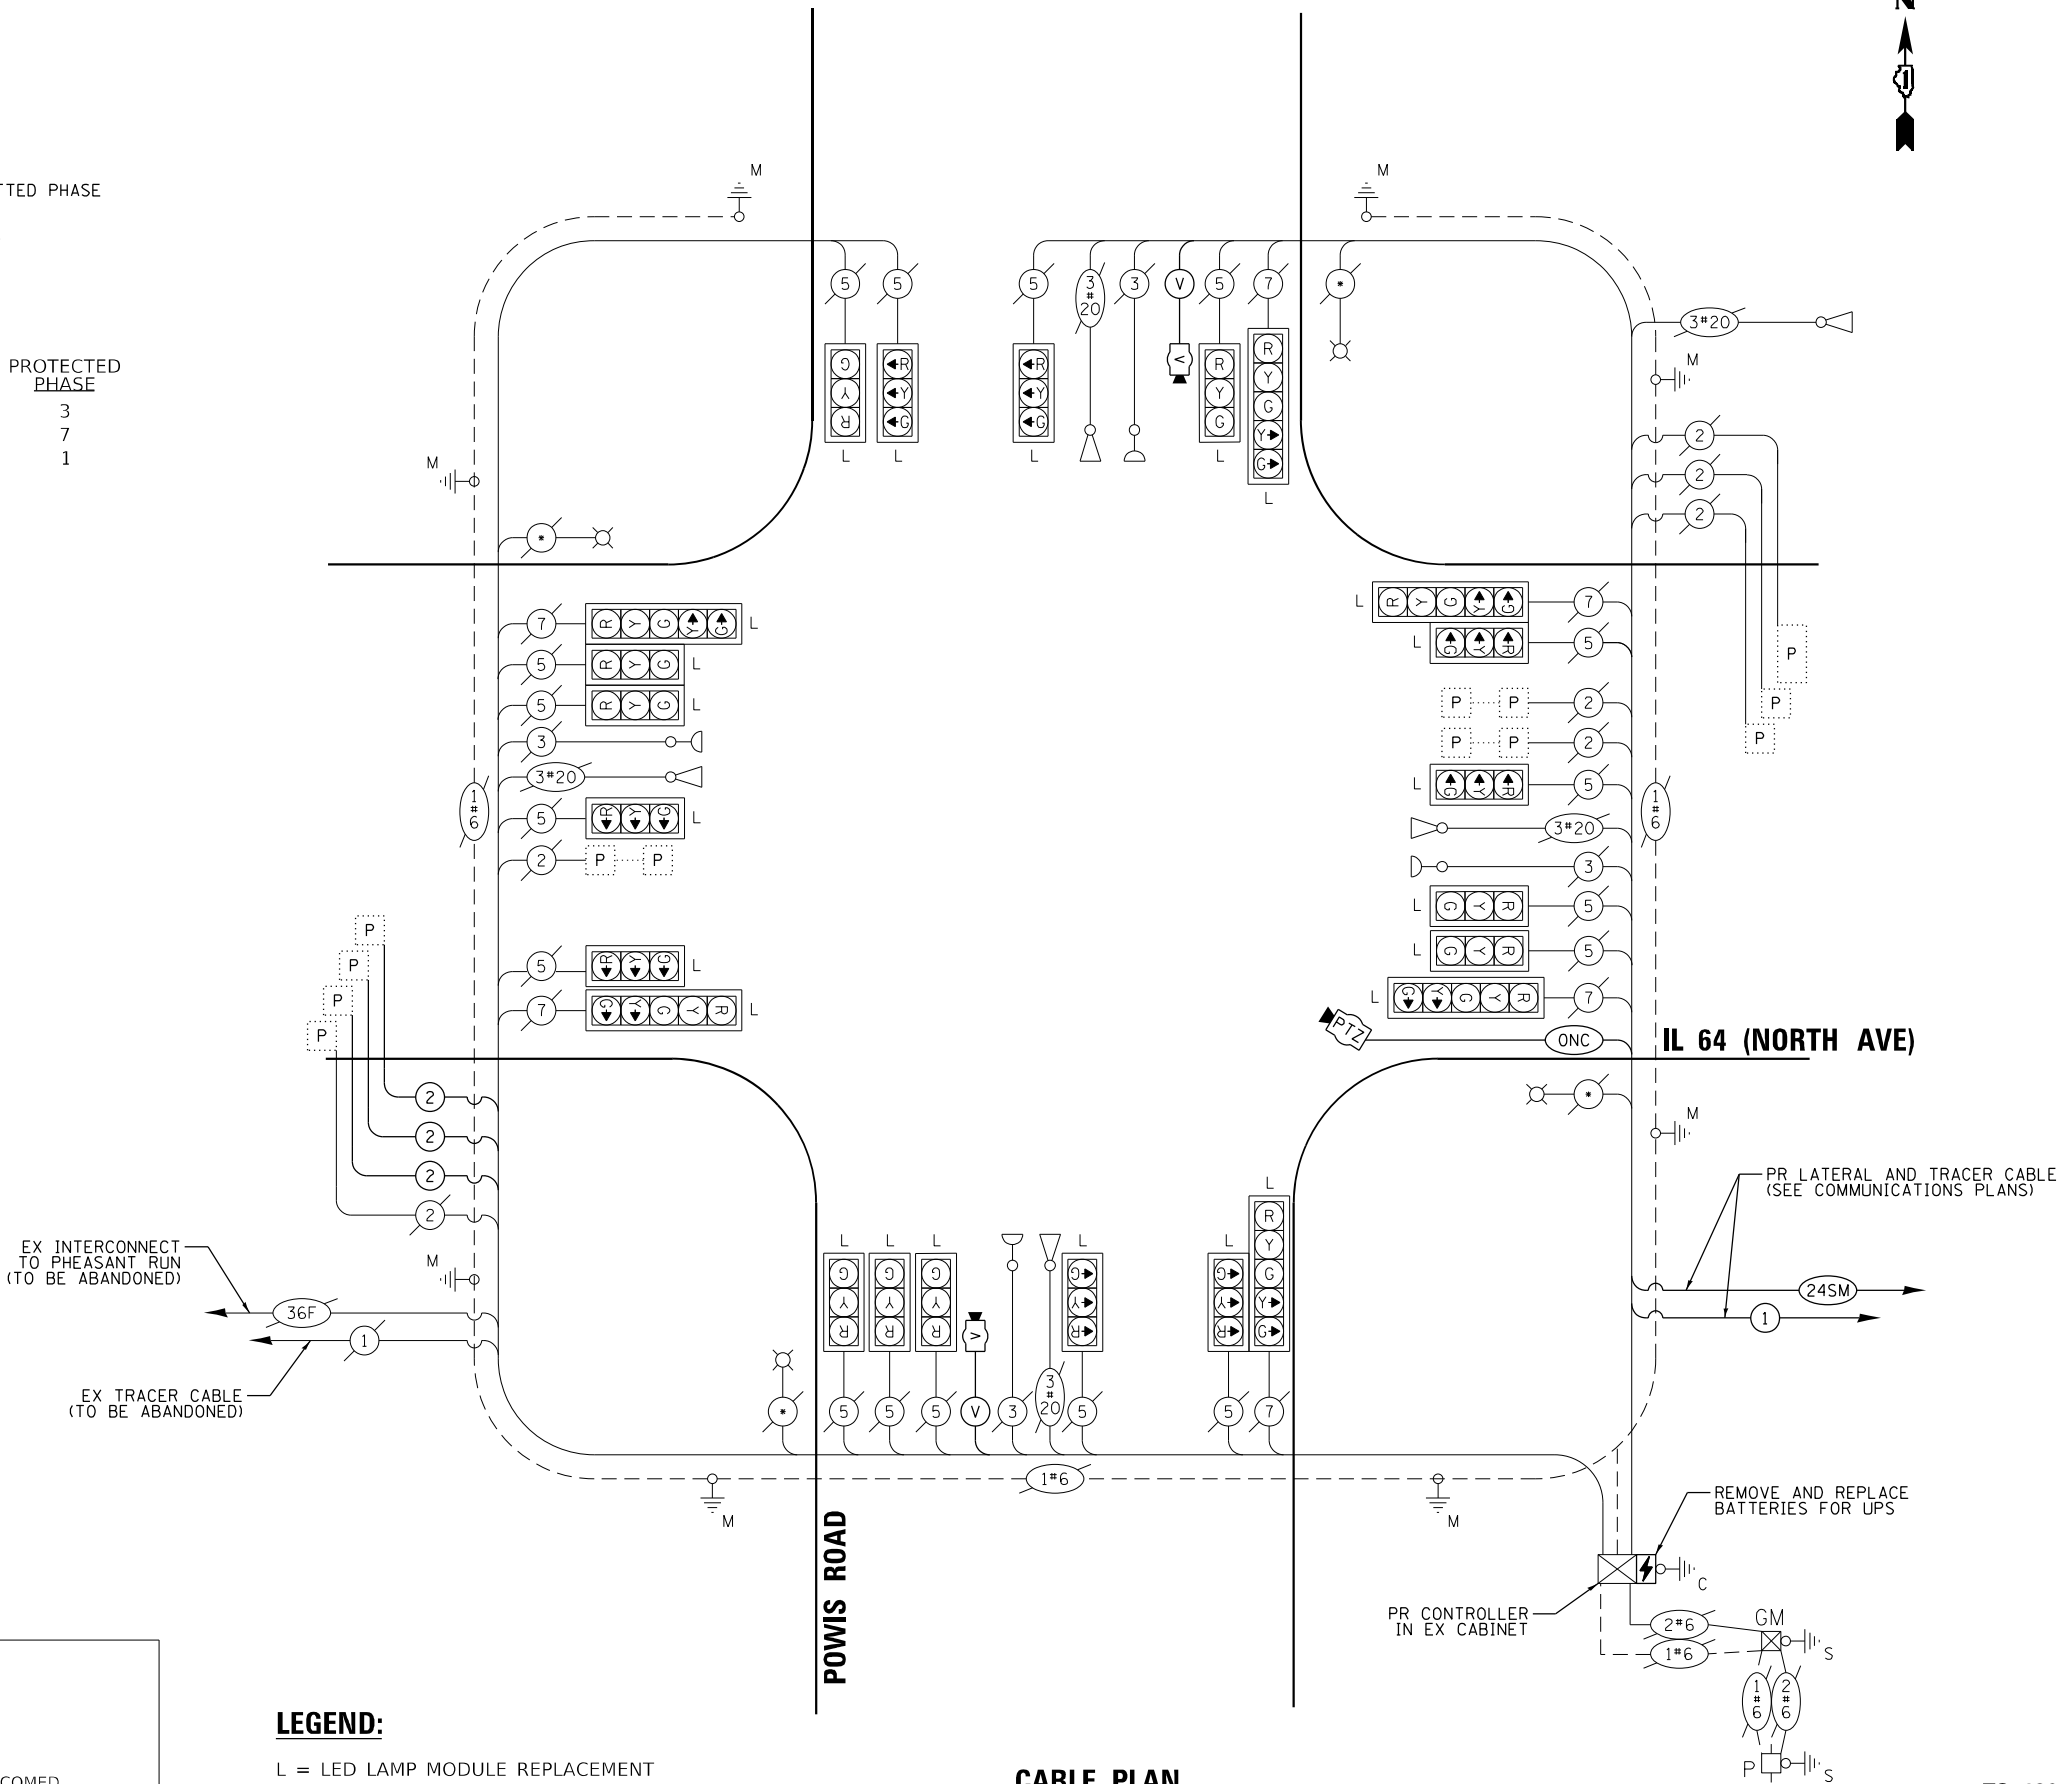

TS 12070
IDOT TACTICS
FORMER EAGLE 2M

KimleyHorn

© 2023 KIMLEY-HORN AND ASSOCIATES, INC.
4001 WILLOW D. ROAD, SUITE 600
WARREN, IL 60555
PHONE: (847) 455-4555
WWW.KIMLEY-HORN.COM

USER NAME =	DESIGNED -	REVISED -
PLOT SCALE =	DRAWN -	REVISED -
PLOT DATE =	CHECKED -	REVISED -
	DATE -	REVISED -

STATE OF ILLINOIS
DEPARTMENT OF TRANSPORTATION

CABLE PLAN, PHASE DESIGNATION DIAGRAM, AND
EMERGENCY VEHICLE PREEMPTION SEQUENCE
IL 64 (NORTH AVE) AND POWIS RD

SCALE: N.T.S. SHEET OF SHEETS STA. TO STA.

F.A.P. RTE.	SECTION	COUNTY	TOTAL SHEETS	SHEET NO.
307	2020-263-SUR, SW&TS	DUPAGE	529	124
				CONTRACT NO. 62N33
		ILLINOIS FED. AID PROJECT		

SCHEDULE OF QUANTITIES

ITEM DESCRIPTION	UNIT	QUANTITY
MAINTENANCE OF EXISTING TRAFFIC SIGNAL INSTALLATION	EACH	1
ELECTRIC CABLE IN CONDUIT, LEAD-IN, NO. 14 1 PAIR	FOOT	1317
INDUCTIVE LOOP DETECTOR	EACH	3
REMOVE EXISTING TRAFFIC SIGNAL EQUIPMENT	EACH	1
REMOVE EXISTING HANDHOLE	EACH	2
CLOSED CIRCUIT TELEVISION DOME CAMERA, HD	EACH	1
LED LAMP MODULE REPLACEMENT	EACH	81
OUTDOOR RATED NETWORK CABLE	FOOT	94
REMOTE CONTROLLED VIDEO SYSTEM	EACH	1
LAYER II (DATALINK) SWITCH	EACH	1
TERMINATE FIBER IN CABINET	EACH	12
TACTICS LICENSE EXPANSION	EACH	1
FULL-ACTUATED CONTROLLER IN EXISTING CABINET	EACH	1
REMOVE AND REPLACE BATTERIES FOR UNINTERRUPTABLE POWER SUPPLY, EXTENDED	EACH	1
FIBER OPTIC INTERCONNECT CENTER, 48 PORT	EACH	1
LED SIGNAL FACE, LENS COVER	EACH	23
VIDEO VEHICLE DETECTION SYSTEM, SINGLE APPROACH	EACH	2
CAMERA MOUNTING ASSEMBLY	EACH	1

**TS 12070
IDOT TACTICS
FORMER EAGLE 2M**


Kimley»Horn © 2021 KIMLEY-HORN AND ASSOCIATES, INC. 4001 SHURE, D ROAD, SUITE 600 VANDERBILT, E.B. 60665 PHONE: 615-481-6550 WWW.KH-PA.COM	USER NAME =	DESIGNED -	REVISED -	STATE OF ILLINOIS DEPARTMENT OF TRANSPORTATION	SCHEDULE OF QUANTITIES IL 64 (NORTH AVE) AND POWIS RD					F.A.P. RTE.	SECTION	COUNTY	TOTAL SHEETS	SHEET NO.
	PLOT SCALE =	DRAWN -	REVISED -							307	2020-263-SUR, SW&TS	DUPAGE	529	125
	PLOT DATE =	CHECKED -	REVISED -		CONTRACT NO. 62N33									
		DATE	REVISED -											
					SCALE: N.T.S.	SHEET	OF	SHEETS	STA.	TO STA.				

1. THE EXISTING TRAFFIC SIGNAL EQUIPMENT SHALL NOT BE REMOVED UNTIL THE PROPOSED TRAFFIC SIGNAL EQUIPMENT IS FULLY OPERATIONAL OR AS DIRECTED BY THE ENGINEER.
2. ALL EXISTING TRAFFIC SIGNAL CABLE NO LONGER REQUIRED SHALL BE REMOVED.
3. THE EXISTING SERVICE METER SHALL BE RELOCATED TO THE PROPOSED GROUND MOUNTED SERVICE CABINET. THE EXISTING SERVICE METER HOUSING SHALL REMAIN AT THE EXISTING TRAFFIC SIGNAL CONTROLLER CABINET AND ALL HOLES BETWEEN THE EXISTING HOUSING AND THE EXISTING CABINET SHALL BE PLUGGED. THIS WORK SHALL BE INCLUDED IN THE PAY ITEM "SERVICE INSTALLATION, GROUND MOUNTED, METERED".

THE FOLLOWING ITEMS SHALL BE REMOVED BY THE CONTRACTOR AND SHALL BE DISPOSED OF BY THEM OUTSIDE THE RIGHT-OF-WAY AT THEIR EXPENSE. THE SALVAGE VALUE OF THE REMOVED EQUIPMENT SHALL BE REFLECTED IN THE CONTRACT BID PRICE.

- THE FOLLOWING ITEMS SHALL BE REMOVED BY THE CONTRACTOR, SHALL REMAIN THE PROPERTY OF THE ILLINOIS DEPARTMENT OF TRANSPORTATION, AND SHALL BE DELIVERED BY THE CONTRACTOR TO IDOT'S TRAFFIC SIGNAL MAINTENANCE CONTRACTOR'S MAIN FACILITY.

 -
- A north arrow pointing upwards with the letter 'N' at the tip. Below it is a scale bar in feet, marked from 0 to 60 in increments of 20. The scale bar is divided into alternating black and white segments.





© 2023 KIMLEY-HORN AND ASSOCIATES, INC.
4201 WHITEFIELD ROAD, SUITE 600
WARRENVILLE, IL 60555
PHONE: 630-487-5550
WWW.KIMLEY-HORN.COM

**STATE OF ILLINOIS
DEPARTMENT OF TRANSPORTATION**

SCALE: 1" = 20'	SHEET	OF	SHEETS	STA.	TO STA.
-----------------	-------	----	--------	------	---------

F.A.P. RTE.	SECTION	COUNTY	TOTAL SHEETS	SHEET NO.
307	2020-263-SUR,SW&TS	DUPAGE	529	126
		CONTRACT NO. 62N33		
ILLINOIS		FED. AID PROJECT		

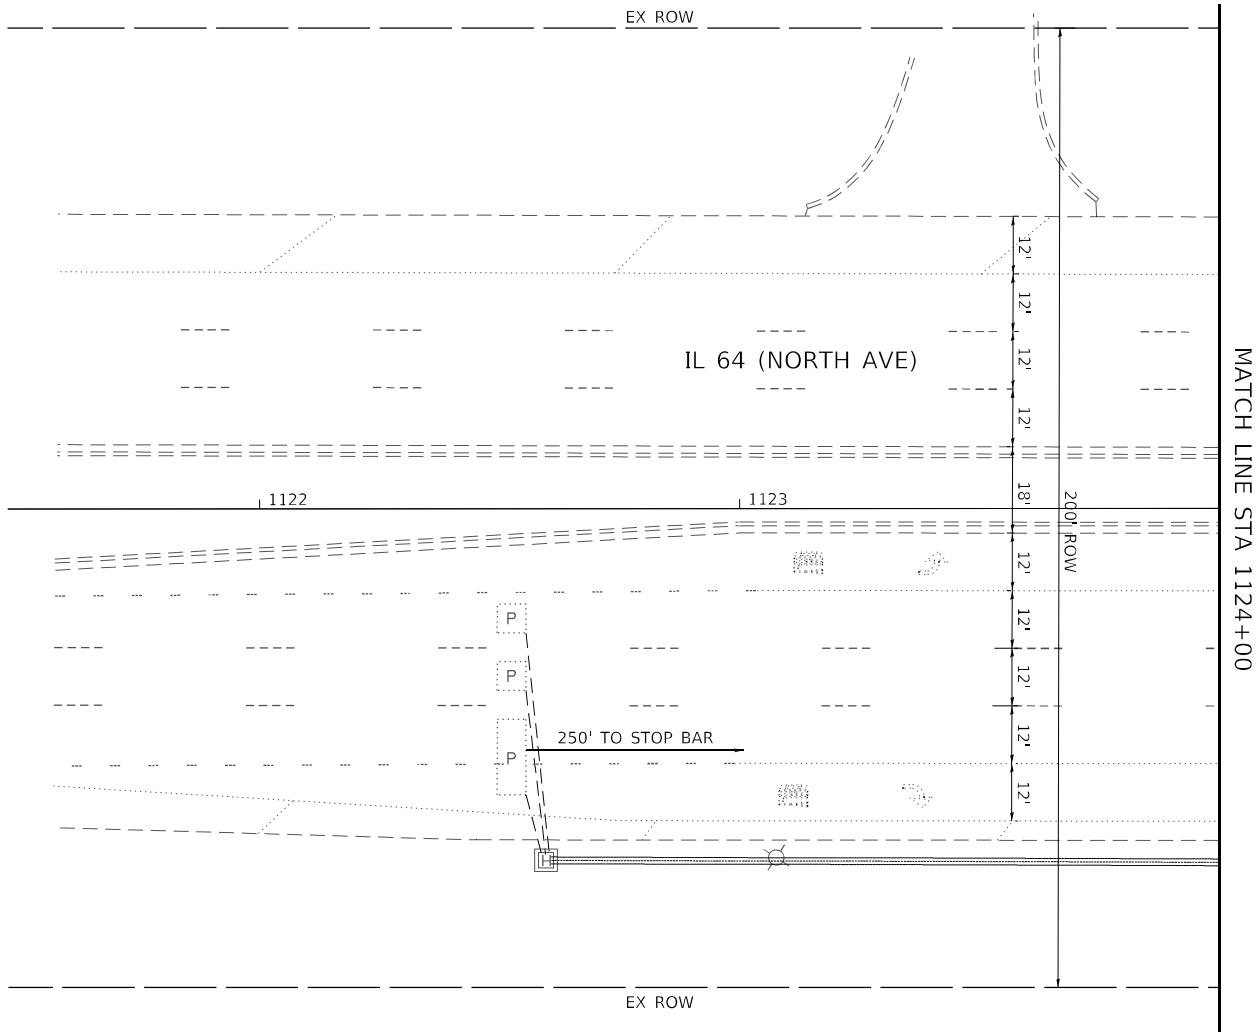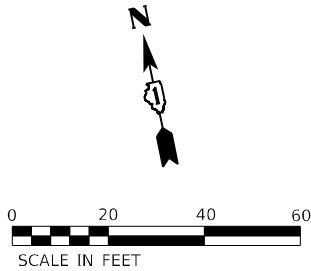

MODEL: Default
FILE NAME: p:\work\pva\bartley.com\k-h-pva-d1\Documents\01 Active Projects\IMW\CHS-168950\00 - IL 64\Phase 1\12 Design\CAD\Plan Streets\Signal\West Corridor_Signal\BID108171-14-14-14-24_KIM.dgn



USER NAME =	DESIGNED -	REVISED -
	DRAWN -	REVISED -
PLOT SCALE =	CHECKED -	REVISED -
PLOT DATE =	DATE -	REVISED -

STATE OF ILLINOIS
DEPARTMENT OF TRANSPORTATION

TRAFFIC SIGNAL EQUIPMENT REMOVAL PLAN IL 64 (NORTH AVE) AND ATLANTIC DR			
SCALE: 1" = 20'	SHEET	OF	SHEETS
STA.		TO STA.	

F.A.P. RTE.	SECTION	COUNTY	TOTAL SHEETS	SHEET NO.
307	2020-263-SUR,SW&TS	DUPAGE	529	127
CONTRACT NO. 62N33				
		ILLINOIS	FED. AID PROJECT	



TS 12373
IDOT TACTICS
FORMER EAGLE 5A

A
LEFT ON
GREEN
ARROW
ONLY

R10-5
30" X 36"
(4 REQUIRED)

NOTES

1. ALL PROPOSED TRAFFIC SIGNAL CABLE SHALL BE ROUTED THROUGH THE PROPOSED CONDUIT.
2. A SEPARATE LEAD-IN CABLE SHALL BE INSTALLED FOR THE DETECTOR LOOPS ON IL 64 (NORTH AVE).
3. PROPOSED CONDUIT SHALL BE SPLICED TO THE EXISTING CONDUIT AND EXTENDED VERTICALLY THROUGH THE PROPOSED FOUNDATION AT THE GROUND MOUNTED SERVICE LOCATION. THE COST OF THE CONDUIT SHALL BE INCLUDED IN THE COST OF "CONCRETE FOUNDATION, TYPE A".

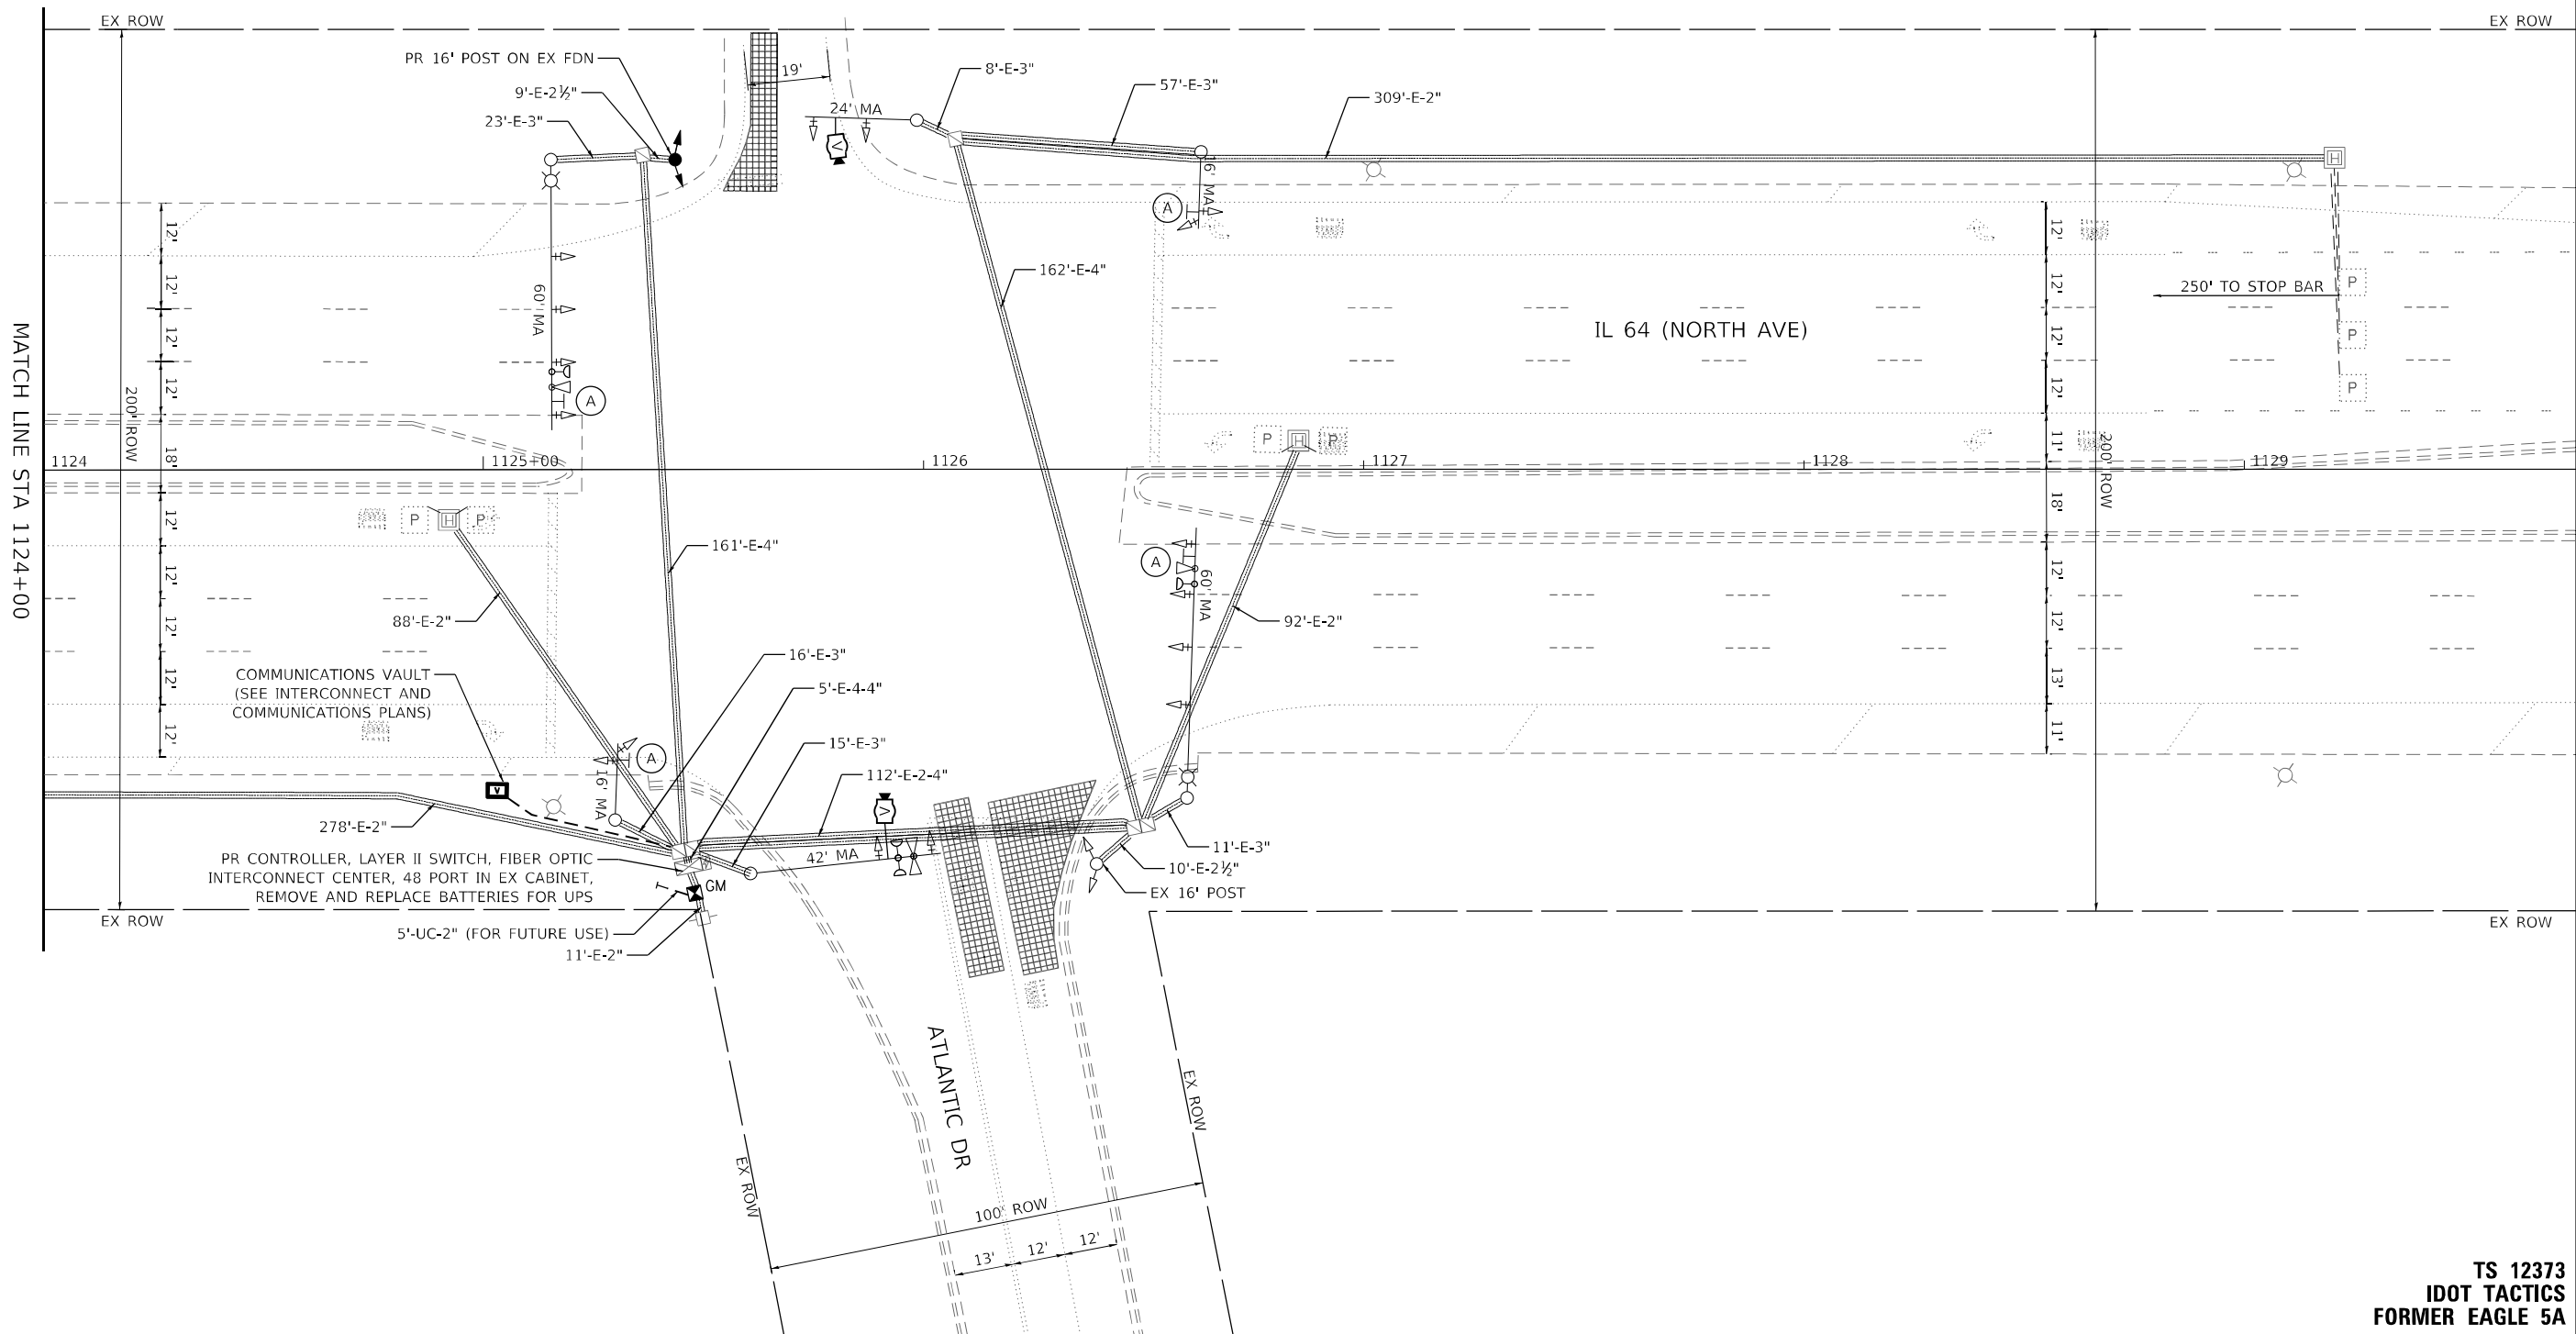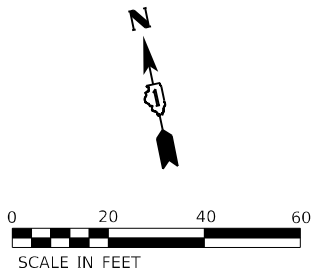

TS 12373
IDOT TACTICS
FORMER EAGLE 5A

Kimley»Horn



USER NAME	=	DESIGNED	-	REVISED	-
DRAWN	-	REVIS	-	REVIS	-
PLOT SCALE	=	CHECKED	-	REVISED	-
PLOT DATE	=	DATE	-	REVISED	-

STATE OF ILLINOIS
DEPARTMENT OF TRANSPORTATION

TRAFFIC SIGNAL MODERNIZATION PLAN
IL 64 (NORTH AVE) AND ATLANTIC DR

SCALE: 1" = 20' SHEET OF SHEETS STA. TO STA.

F.A.P. RTE.	SECTION	COUNTY	TOTAL SHEETS	SHEET NO.
307	2020-263-SUR, SW&TS	DUPAGE	529	128
CONTRACT NO. 62N33				
ILLINOIS FED. AID PROJECT				

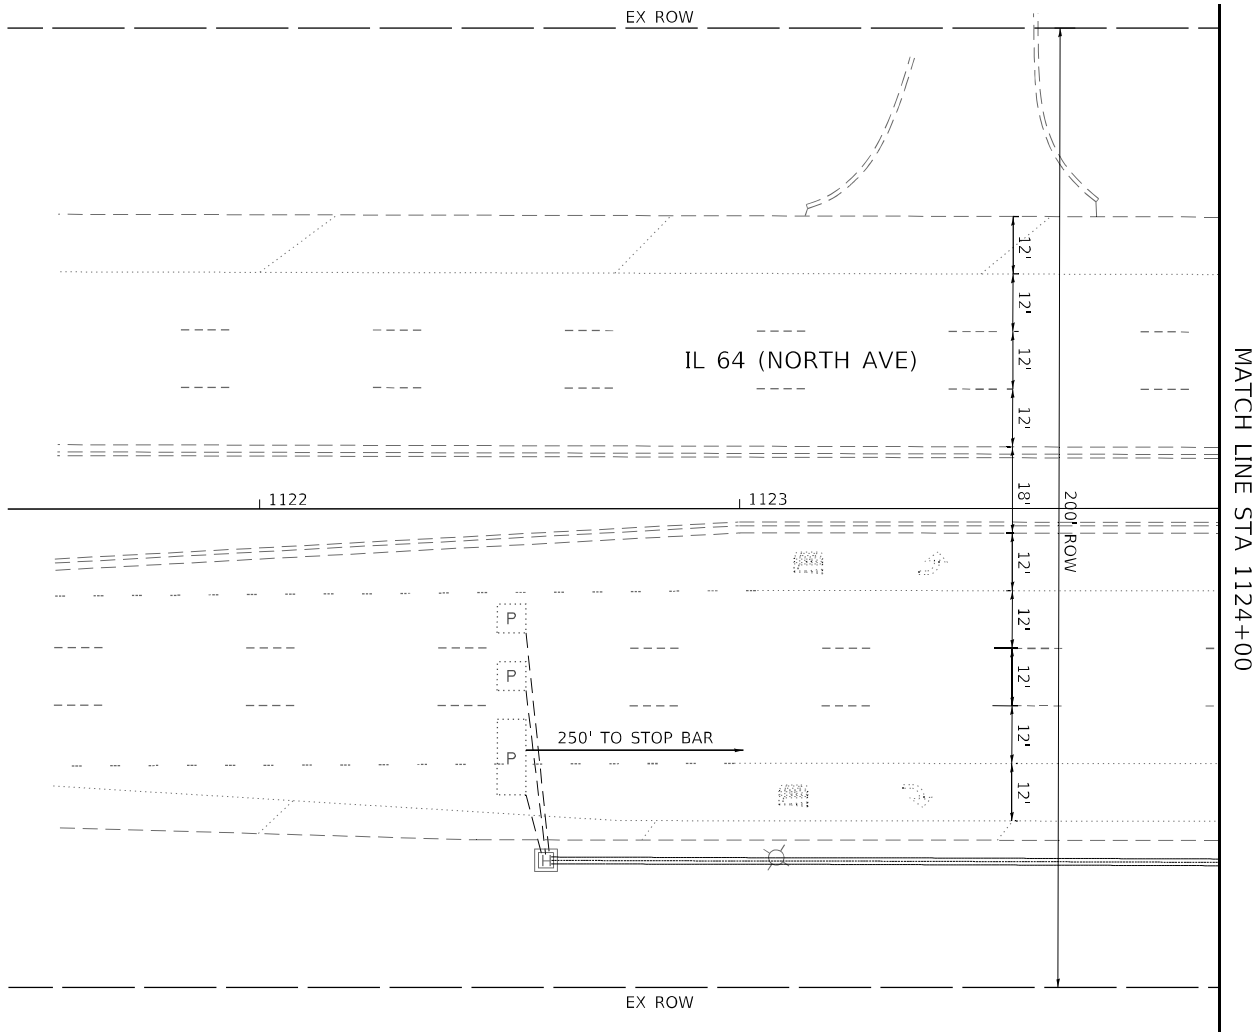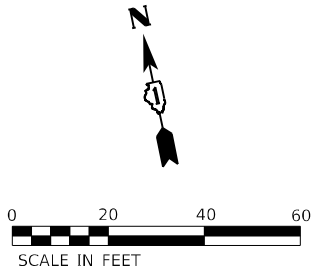

MODEL: Default
FILE NAME: p:\bentley.com\khp\p4\1\Documents\01 Active Projects\IMW\CHS-168950\00 - IL 64\Phase 1\2 Design\CAD\Plan Streets\Signal\West Corridor_Signal\010817-14\11-16_KIM.dgn



USER NAME	=	DESIGNED	-	REVISED	-
		DRAWN	-	REVISED	-
PLOT SCALE	=	CHECKED	-	REVISED	-
PLOT DATE	=	DATE	-	REVISED	-

STATE OF ILLINOIS
DEPARTMENT OF TRANSPORTATION

TRAFFIC SIGNAL MODERNIZATION PLAN
IL 64 (NORTH AVE) AND ATLANTIC DR

SCALE: 1" = 20' SHEET OF SHEETS STA. TO STA.

F.A.P. RTE.	SECTION	COUNTY	TOTAL SHEETS	SHEET NO.
307	2020-263-SUR,SW&TS	DUPAGE	529	129
CONTRACT NO. 62N33				
		ILLINOIS	FED. AID PROJECT	

TS 12373
IDOT TACTICS
FORMER EAGLE 5A

 PROTECTED PHASE
 PROTECTED/PERMITTED PHASE
 PEDESTRIAN PHASE
 OVERLAP

$$\begin{array}{ccccc} \text{OVERLAP} & & \text{PERMISSIVE} & & \text{PROTECTED} \\ \text{LETTER} & & \text{PHASE} & & \text{PHASE} \\ D & = & 8 & + & 1 \end{array}$$

TYPE	QUANTITY	UNIT WATTAGE	TOTAL WATTAGE
SIGNAL HEAD 1 OR 3-SECTION	18	11	198
4-SECTION	-	14	-
5-SECTION	2	13	26
PROGRAMMABLE 3-SECTION	-	22	-
4-SECTION	-	32	-
5-SECTION	-	28	-
PEDESTRIAN SIGNAL	-	15	-
CONTROLLER	1	150	150
MASTER CONTROLLER	-	100	-
UPS	1	25	25
DETECTION VIDEO	2	20	40
BLANK-OUT SIGN	-	25	-
NETWORK SWITCH LAYER II OR III	1	35	35
CELLULAR MODEM	-	15	-
PTZ	-	75	-
TOTAL UPS SIZING			474
UPS CHARGING	1	225	225
BATTERY HEATER MAT	1	180	180
CABINET HEATER	1	200	200
FLASHER	-	15	-
LED STREET NAME SIGN	-	120	-
LUMINAIRE	-	240	-

ENERGY SUPPLY: COMPANY: COMED
PHONE: (866) 639-3532
ACCOUNT NUMBER: 73470-49055

(NOT TO SCALE)

L = LED LAMP MODULE REPLACEMENT
* = ROADWAY LIGHTING CABLE

**CABLE PLAN, PHASE DESIGNATION DIAGRAM, AND
EMERGENCY VEHICLE PREEMPTION SEQUENCE
IL 64 (NORTH AVE) AND ATLANTIC DR**

SCALE: N.T.S.	SHEET	OF	SHEETS	STA.	TO STA.
---------------	-------	----	--------	------	---------

F.A.P. RTE.	SECTION	COUNTY	TOTAL SHEETS	SHEET NO.
307	2020-263-SUR,SW&TS	DUPAGE	529	130
		CONTRACT NO. 62N33		
		ILLINOIS FED. AID PROJECT		

ALL DIMENSIONS ARE IN INCHES UNLESS OTHERWISE NOTED





DESIGN SERIES	AREA (SQ FT)	SIGN PANEL TYPE	SHEETING TYPE	QTY. REQUIRED
D	12.5	2	ZZ	2

ITEM DESCRIPTION	UNIT	QUANTITY
SIGN PANEL - TYPE 2	SQ FT	25
UNDERGROUND CONDUIT, GALVANIZED STEEL, 2" DIA.	FOOT	5
MAINTENANCE OF EXISTING TRAFFIC SIGNAL INSTALLATION	EACH	1
ELECTRIC CABLE IN CONDUIT, SERVICE, NO. 6 2 C	FOOT	38
ELECTRIC CABLE IN CONDUIT, EQUIPMENT GROUNDING CONDUCTOR, NO. 6 1C	FOOT	38
TRAFFIC SIGNAL POST, GALVANIZED STEEL 16 FT.	EACH	1
CONCRETE FOUNDATION, TYPE A	FOOT	4
SIGNAL HEAD, LED, 1-FACE, 3-SECTION, BRACKET MOUNTED	EACH	2
REMOVE ELECTRIC CABLE FROM CONDUIT	FOOT	38
REMOVE EXISTING TRAFFIC SIGNAL EQUIPMENT	EACH	1
REMOVE EXISTING HANDHOLE	EACH	1
LED LAMP MODULE REPLACEMENT	EACH	58
SERVICE INSTALLATION, GROUND MOUNTED, METERED	EACH	1
LAYER II (DATALINK) SWITCH	EACH	1
TERMINATE FIBER IN CABINET	EACH	12
TACTICS LICENSE EXPANSION	EACH	1
FULL-ACTUATED CONTROLLER IN EXISTING CABINET	EACH	1
REMOVE AND REPLACE BATTERIES FOR UNINTERRUPTABLE POWER SUPPLY, EXTENDED	EACH	1
FIBER OPTIC INTERCONNECT CENTER, 48 PORT	EACH	1
LED SIGNAL FACE, LENS COVER	EACH	20
VIDEO VEHICLE DETECTION SYSTEM, SINGLE APPROACH	EACH	2

1. THE EXISTING TRAFFIC SIGNAL EQUIPMENT SHALL NOT BE REMOVED UNTIL THE PROPOSED TRAFFIC SIGNAL EQUIPMENT IS FULLY OPERATIONAL OR AS DIRECTED BY THE ENGINEER.
2. ALL EXISTING TRAFFIC SIGNAL CABLE NO LONGER REQUIRED SHALL BE REMOVED.



F.A.P. RTE.	SECTION	COUNTY	TOTAL SHEETS	SHEET NO.
307	2020-263-SUR,SW&TS	DUPAGE	529	1322
		CONTRACT NO. 62N33		
ILLINOIS		FED. AID PROJECT		

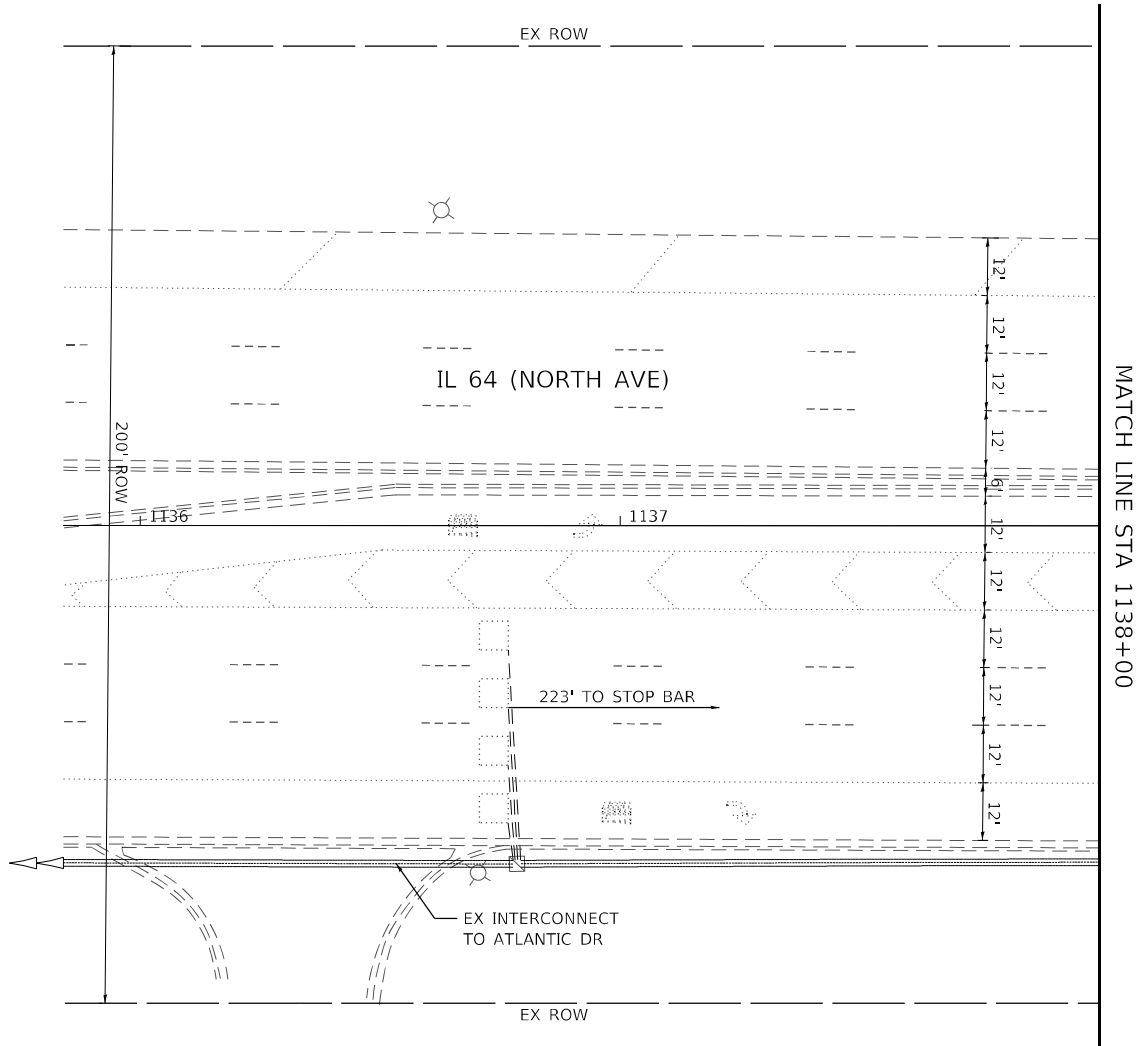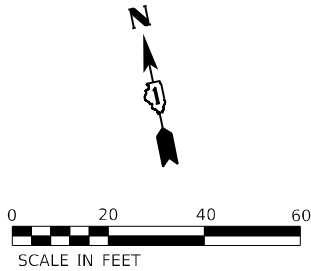

MODEL: Default
FILE: h:\mhc\p\h-pw\bartley.com\h-pw-d\1\Documents\01 Active Projects\MW\CL-S-168950\00 - IL 64\Phase II\2 Design\CAD\Plan Streets\Signal\West Corridor Signal\01081714-IL-64-30_KIM.dgn



USER NAME	=	DESIGNED	-	REVISED	-
		DRAWN	-	REVISED	-
PLOT SCALE	=	CHECKED	-	REVISED	-
PLOT DATE	=	DATE	-	REVISED	-


STATE OF ILLINOIS
DEPARTMENT OF TRANSPORTATION

TRAFFIC SIGNAL EQUIPMENT REMOVAL PLAN
IL 64 (NORTH AVE) AND TERESA LN/MENARDS ENTR

SCALE: 1" = 20' SHEET OF SHEETS STA. TO STA.

F.A.P. RTE.	SECTION	COUNTY	TOTAL SHEETS	SHEET NO.
307	2020-263-SUR, SW&TS	DUPAGE	529	133
CONTRACT NO. 62N33				
ILLINOIS FED. AID PROJECT				

TS 12377
IDOT TACTICS
FORMER EAGLE 5A

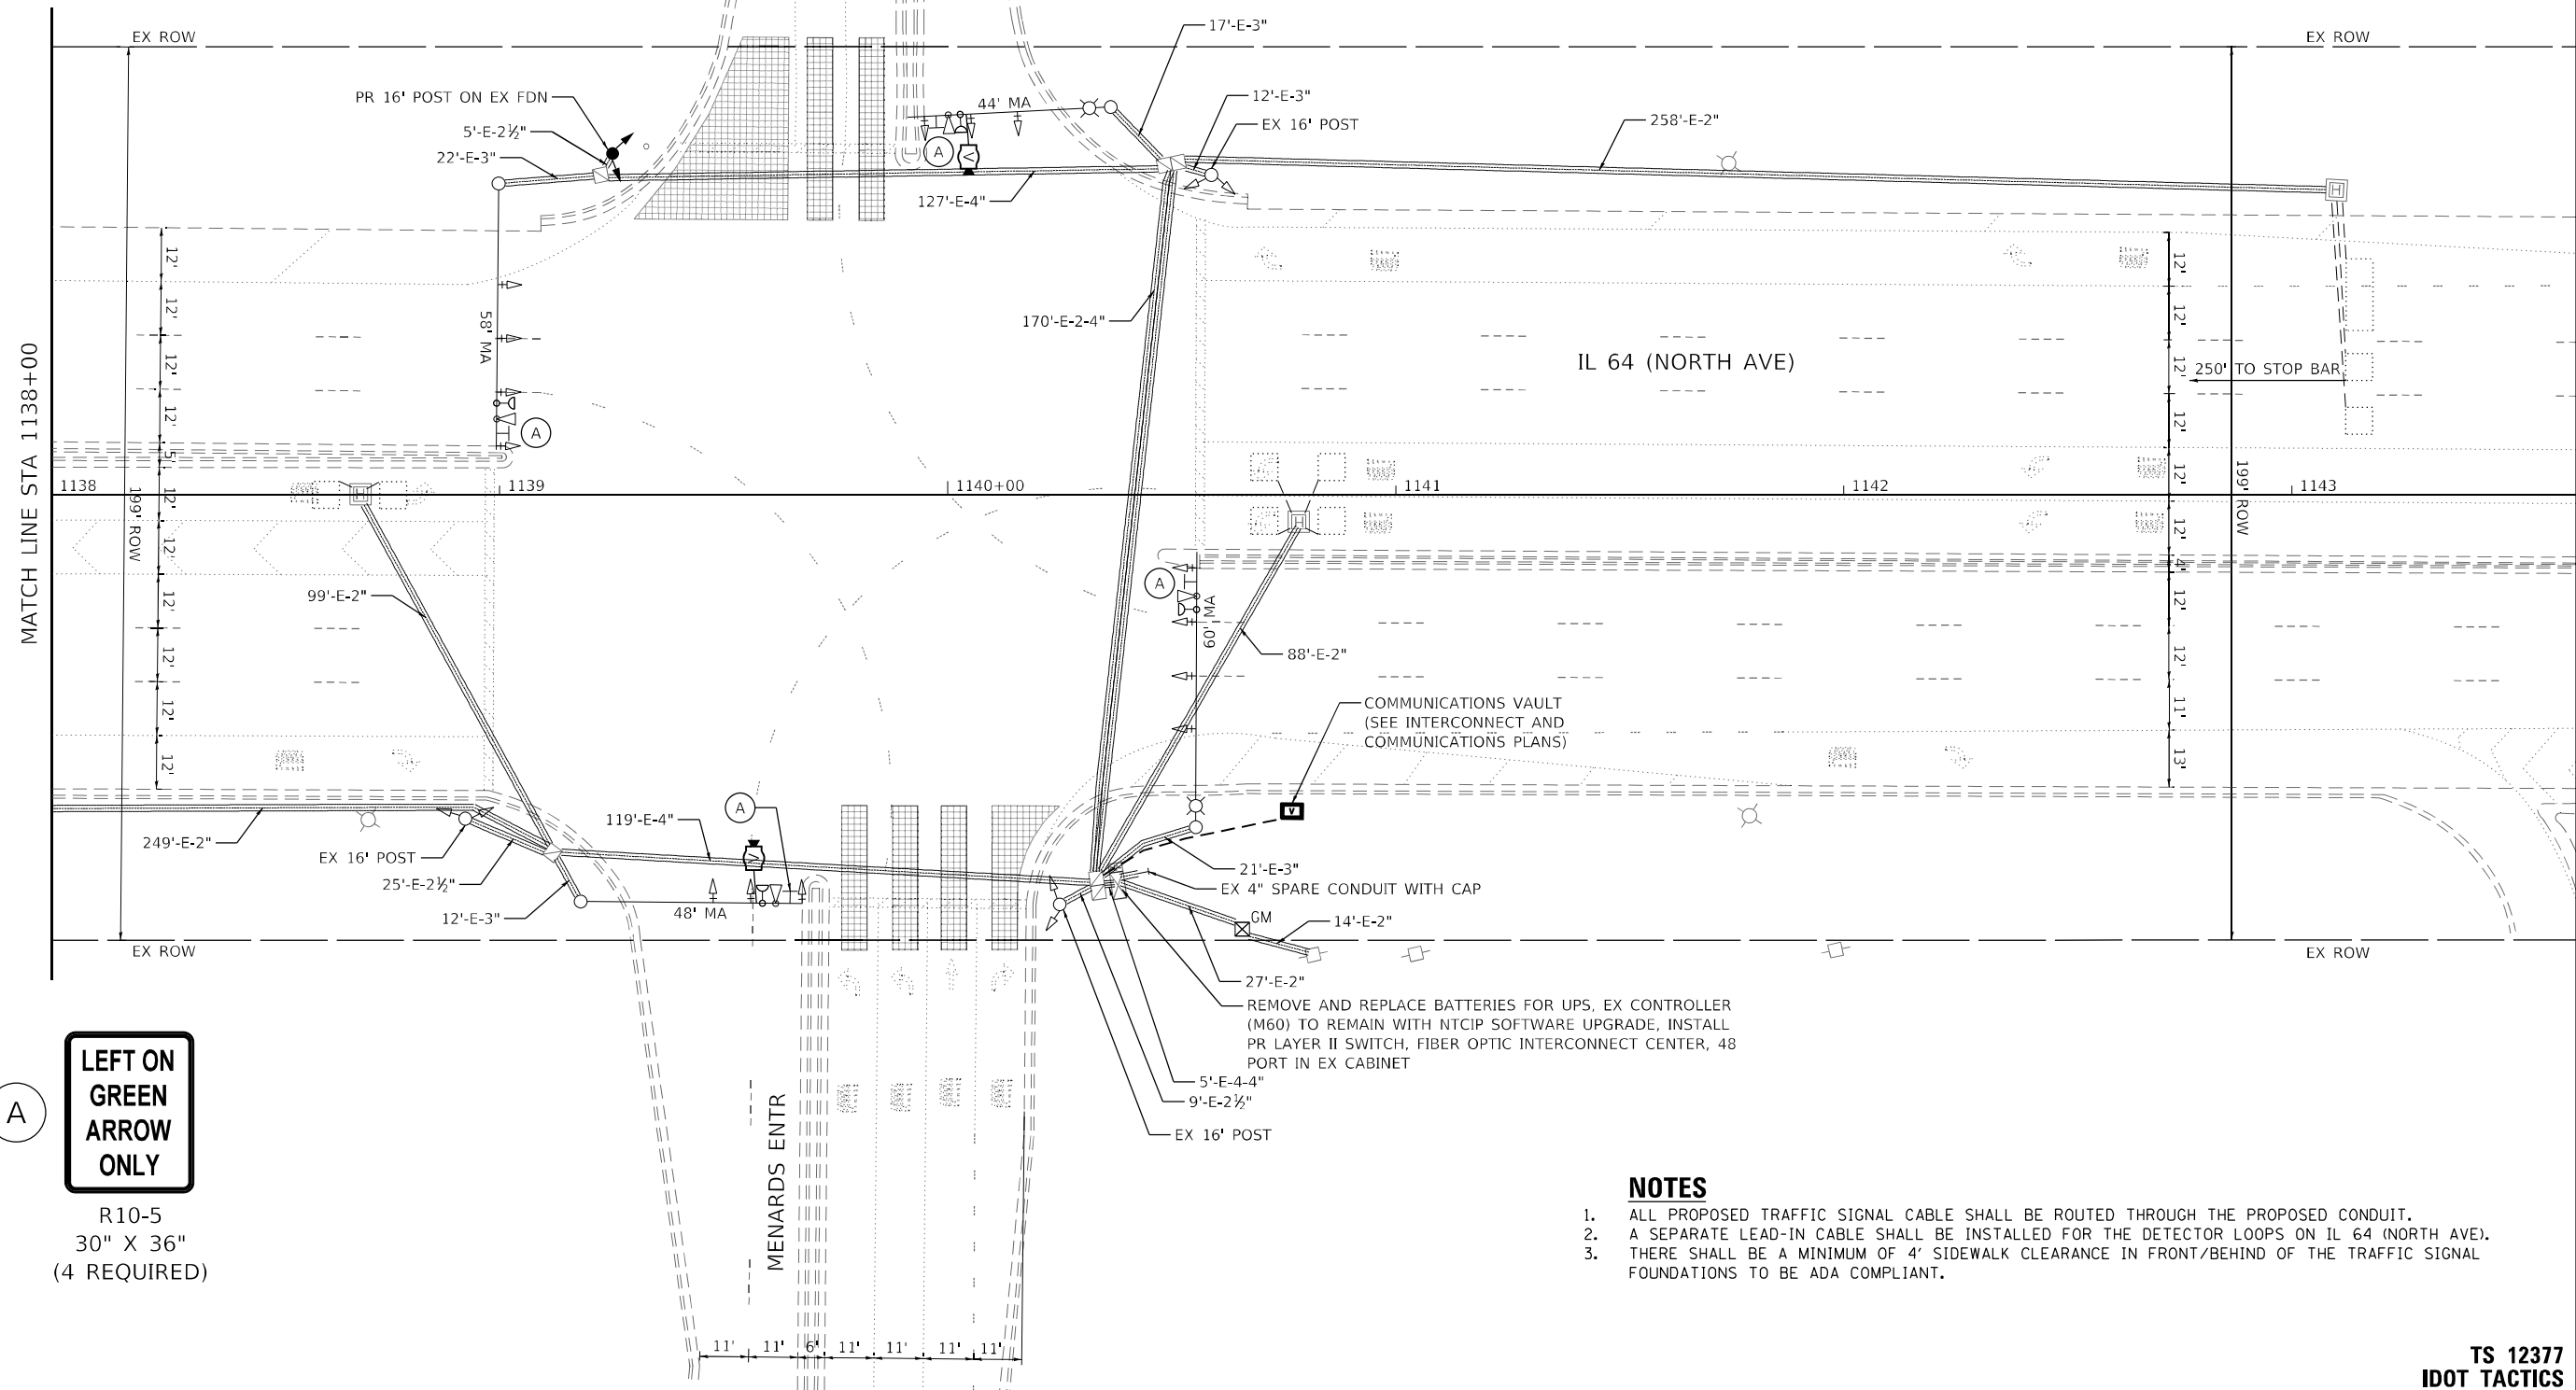

**LEFT ON
GREEN
ARROW
ONLY**

R10-5
30" X 36"
(4 REQUIRED)

- NOTES**
1. ALL PROPOSED TRAFFIC SIGNAL CABLE SHALL BE ROUTED THROUGH THE PROPOSED CONDUIT.
 2. A SEPARATE LEAD-IN CABLE SHALL BE INSTALLED FOR THE DETECTOR LOOPS ON IL 64 (NORTH AVE).
 3. THERE SHALL BE A MINIMUM OF 4' SIDEWALK CLEARANCE IN FRONT/BEHIND OF THE TRAFFIC SIGNAL FOUNDATIONS TO BE ADA COMPLIANT.

**TS 12377
IDOT TACTICS
FORMER EAGLE 5A**

MODEL: Default
FILE: \\hwy-01\hwy-bentley.com\hwy-01\Documents\01 Active Projects\IL64\IL64-01\Drawings\Signal\West Corridor Signal\1138+00 to 1143+00.dgn
© 2021 KIMLEY-HORN AND ASSOCIATES, INC.
4001 WILSON ROAD, SUITE 600
WARREN, IL 60555
PHONE: 815.447.4555
WWW.KIMLEY-HORN.COM





USER NAME =	DESIGNED -	REVISED -
DRAWN -	REVISOR -	
PLOT SCALE =	CHECKED -	REVISED -
PLOT DATE =	DATE -	REVISED -

**STATE OF ILLINOIS
DEPARTMENT OF TRANSPORTATION**

**TRAFFIC SIGNAL MODERNIZATION PLAN
IL 64 (NORTH AVE) AND TERESA LN/MENARDS ENTR**

SCALE: 1" = 20' SHEET OF SHEETS STA. TO STA.

F.A.P. RTE.	SECTION	COUNTY	TOTAL SHEETS	SHEET NO.
307	2020-263-SUR, SW&TS	DUPAGE	529	134
CONTRACT NO. 62N33				
ILLINOIS FED. AID PROJECT				

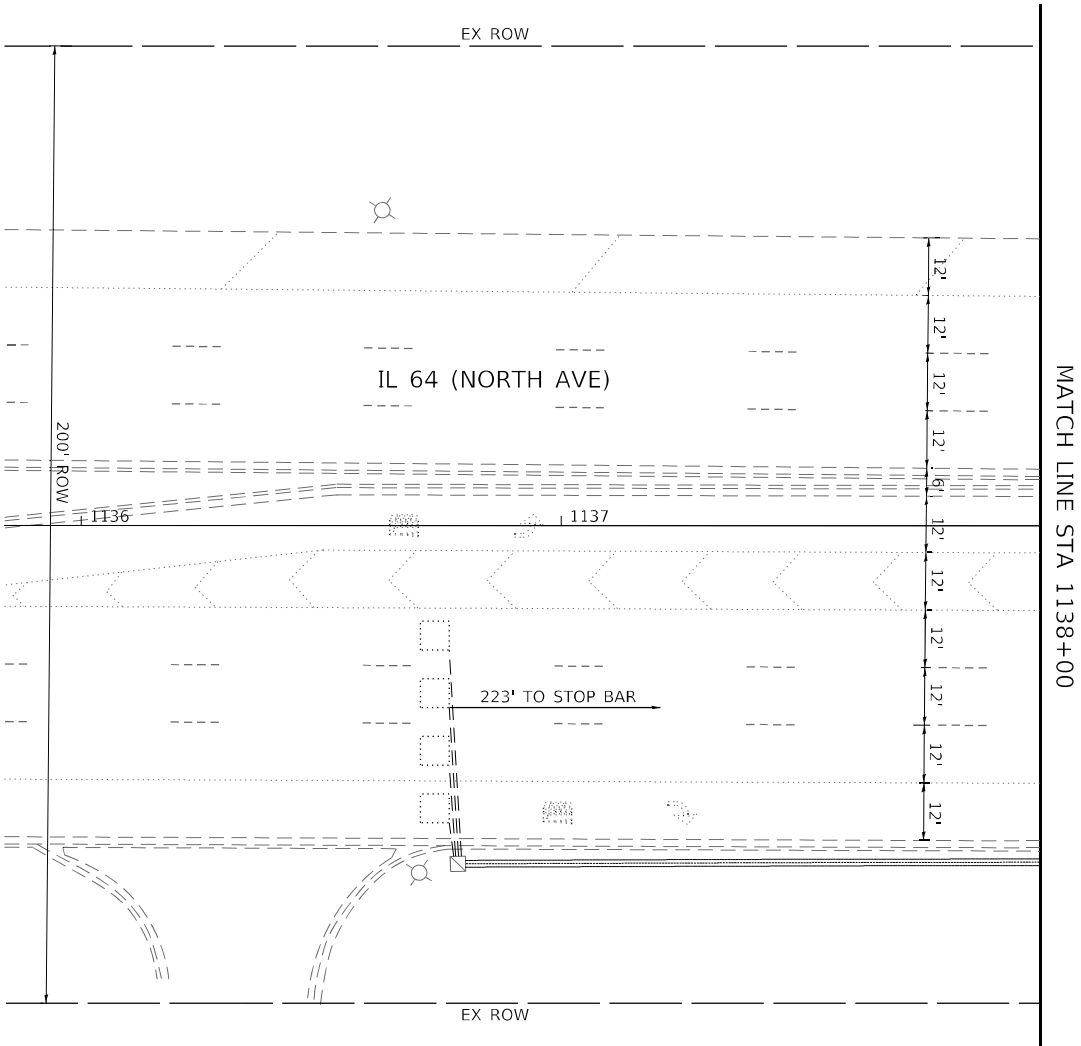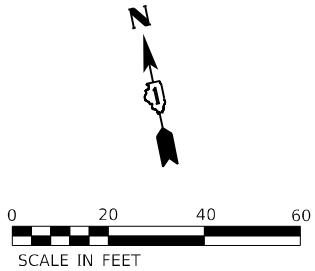

MODEL: Default
FILE NAME: p:\sub-pw\bartley.com\k-h-pw-d\1\Documents\01 Active Projects\MW\CL-S-160950\00 - IL 64\Phase 1\2 Design\CAD\Plan Streets\Signal\West Corridor_Signal\01081714-IL-64-32_KIM.dgn



USER NAME	=	DESIGNED	-	REVISED	-
		DRAWN	-	REVISED	-
PLOT SCALE	=	CHECKED	-	REVISED	-
PLOT DATE	=	DATE	-	REVISED	-

STATE OF ILLINOIS
DEPARTMENT OF TRANSPORTATION


TRAFFIC SIGNAL MODERNIZATION PLAN
IL 64 (NORTH AVE) AND TERESA LN/MENARDS ENTR

SCALE: 1" = 20' SHEET OF SHEETS STA. TO STA.


F.A.P. RTE.	SECTION	COUNTY	TOTAL SHEETS	SHEET NO.
307	2020-263-SUR,SW&TS	DUPAGE	529	135
CONTRACT NO. 62N33				
		ILLINOIS	FED. AID PROJECT	

TS 12377
IDOT TACTICS
FORMER EAGLE 5A

EXISTING AND PROPOSED CONTROLLER SEQUENCE

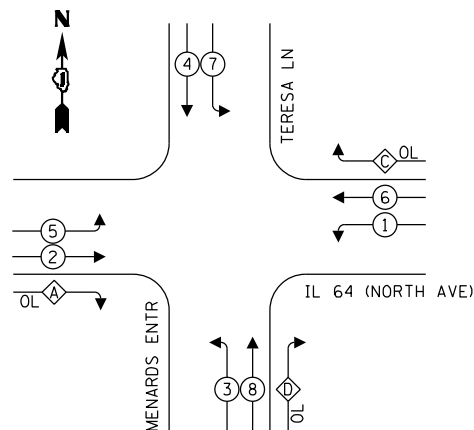


LEGEND:

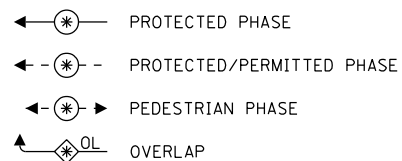

OVERLAP LETTER		PERMISSIVE PHASE		PROTECTED PHASE
A	=	2	+	3
C	=	6	+	7
D	=	8	+	1

EXISTING AND PROPOSED EMERGENCY VEHICLE PREEMPTION SEQUENCE

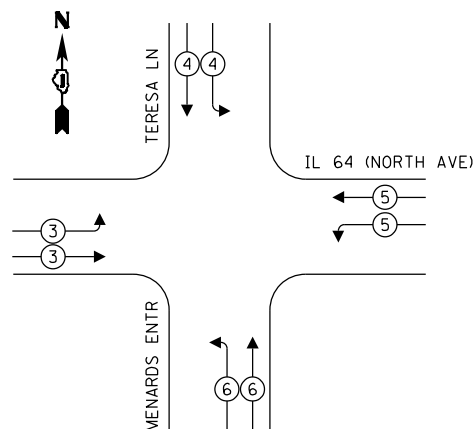

TRAFFIC SIGNAL ELECTRICAL SERVICE REQUIREMENTS

TYPE	QUANTITY	UNIT WATTAGE	TOTAL WATTAGE
SIGNAL HEAD 1 OR 3-SECTION	16	11	176
4-SECTION	-	14	-
5-SECTION	6	13	78
PROGRAMMABLE 3-SECTION	-	22	-
4-SECTION	-	32	-
5-SECTION	-	28	-
PEDESTRIAN SIGNAL	-	15	-
CONTROLLER	1	150	150
MASTER CONTROLLER	-	100	-
UPS	1	25	25
DETECTION VIDEO	2	20	40
BLANK-OUT SIGN	-	25	-
NETWORK SWITCH LAYER II OR III	1	35	35
CELLULAR MODEM	-	15	-
TOTAL UPS SIZING			504
UPS CHARGING	1	225	225
BATTERY HEATER MAT	1	180	180
CABINET HEATER	1	200	200
FLASHER	-	15	-
LED STREET NAME SIGN	-	120	-
LUMINAIRE	-	240	-
TOTAL SERVICE WIRE SIZING			1109

ENERGY COSTS TO:
CITY OF WEST CHICAGO
475 MAIN ST
WEST CHICAGO, IL 60185


ENERGY SUPPLY: COMPANY: COMED
PHONE: (866) 639-3532
ACCOUNT NUMBER: 73470-49055

LEGEND:

L = LED LAMP MODULE REPLACEMENT
* = ROADWAY LIGHTING CABLE

CABLE PLAN

(NOT TO SCALE)

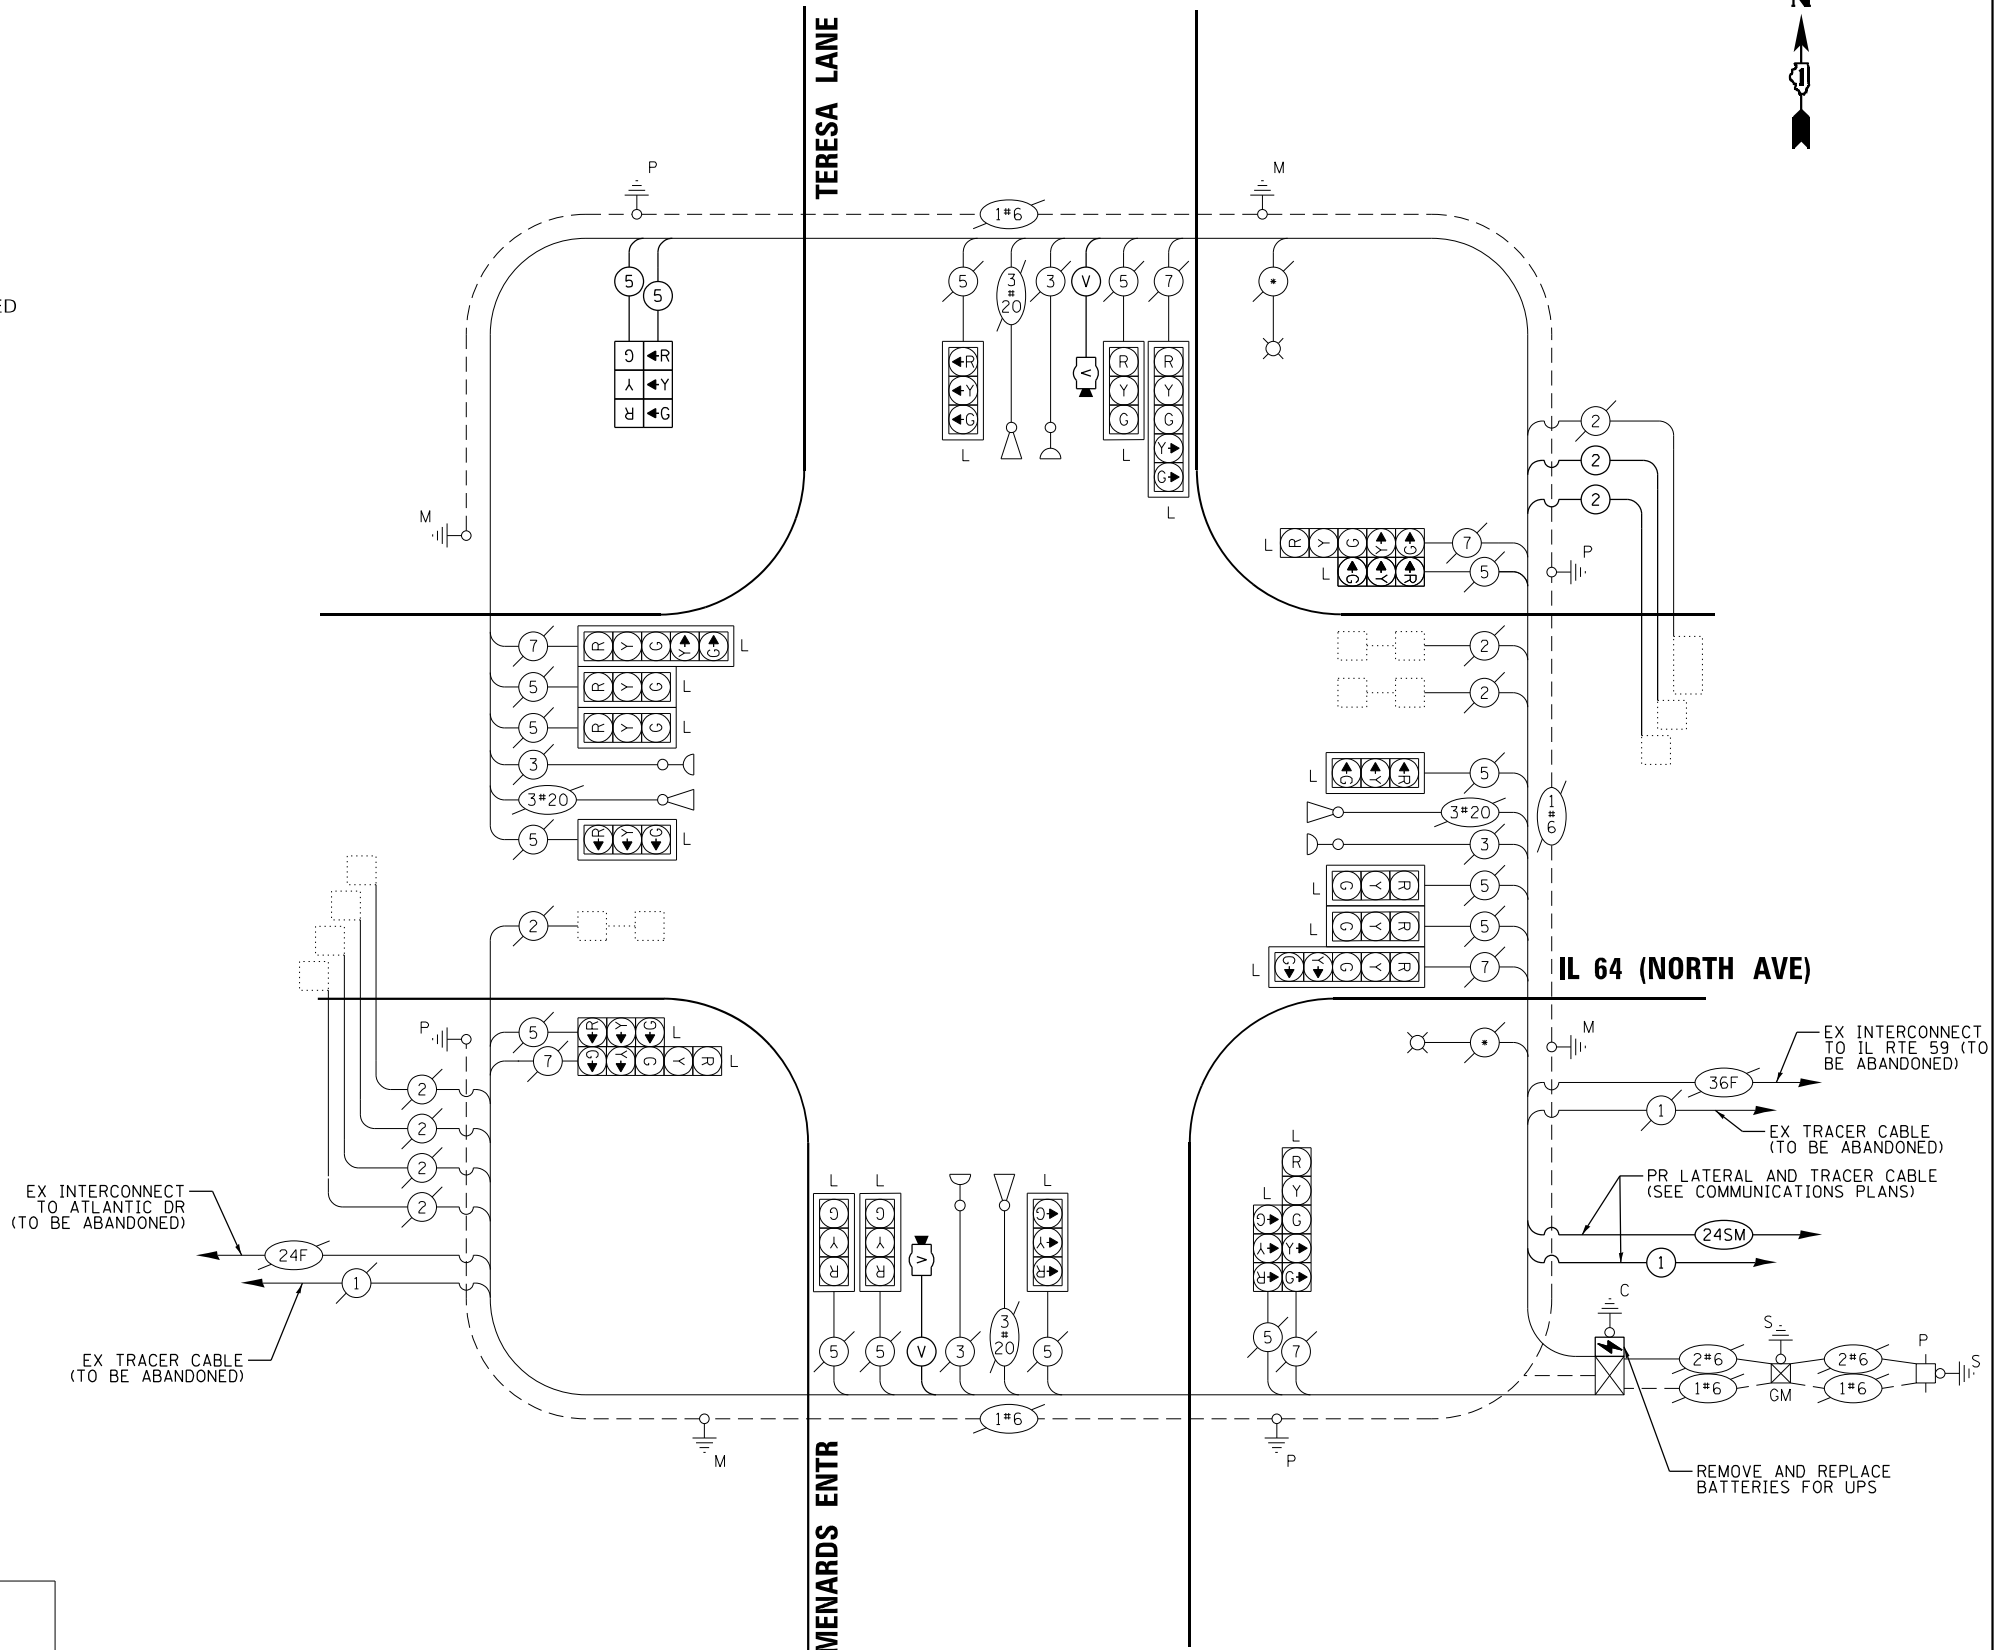

TS 12377
IDOT TACTICS
FORMER EAGLE 5A

Kimley»»Horn

© 2023 KIMLEY-HORN AND ASSOCIATES, INC.
4201 WINTERFIELD ROAD, SUITE 600
WARRENVILLE, IL 60555
PHONE: 630-487-5550
WWW.KIMLEY-HORN.COM

USER NAME	=	
PLOT SCALE	=	
PLOT DATE	=	

DESIGNED	-
DRAWN	-
CHECKED	-
DATE	-

REVISED	-
REVISED	-
REVISED	-
REVISED	-

**STATE OF ILLINOIS
DEPARTMENT OF TRANSPORTATION**

**CABLE PLAN, PHASE DESIGNATION DIAGRAM, AND
EMERGENCY VEHICLE PREEMPTION SEQUENCE
IL 64 (NORTH AVE) AND TERESA LN/MENARDS ENTR**

SCALE: N.T.S.	SHEET	OF	SHEETS	STA.	TO STA.
---------------	-------	----	--------	------	---------


F.A.P. RTE.	SECTION	COUNTY	TOTAL SHEETS	SHEET NO.
307	2020-263-SUR,SW&TS	DUPAGE	529	136
		CONTRACT NO. 62N33		
		ILLINOIS	FED. AID PROJECT	

SCHEDULE OF QUANTITIES

ITEM DESCRIPTION	UNIT	QUANTITY
MAINTENANCE OF EXISTING TRAFFIC SIGNAL INSTALLATION	EACH	1
ELECTRIC CABLE IN CONDUIT, SIGNAL NO. 14 5C	FOOT	730
ELECTRIC CABLE IN CONDUIT, LEAD-IN, NO. 14 1 PAIR	FOOT	1377
TRAFFIC SIGNAL POST, GALVANIZED STEEL 16 FT.	EACH	1
SIGNAL HEAD, LED, 1-FACE, 3-SECTION, BRACKET MOUNTED	EACH	2
INDUCTIVE LOOP DETECTOR	EACH	2
REMOVE ELECTRIC CABLE FROM CONDUIT	FOOT	730
REMOVE EXISTING TRAFFIC SIGNAL EQUIPMENT	EACH	1
LED LAMP MODULE REPLACEMENT	EACH	72
LAYER II (DATA LINK) SWITCH	EACH	1
TERMINATE FIBER IN CABINET	EACH	12
UPGRADE EXISTING CONTROLLER TO NTCIP SPECIAL	EACH	1
TACTICS LICENSE EXPANSION	EACH	1
REMOVE AND REPLACE BATTERIES FOR UNINTERRUPTABLE POWER SUPPLY, EXTENDED	EACH	1
FIBER OPTIC INTERCONNECT CENTER, 48 PORT	EACH	1
LED SIGNAL FACE, LENS COVER	EACH	22
VIDEO VEHICLE DETECTION SYSTEM, SINGLE APPROACH	EACH	2

TS 12377
IDOT TACTICS
FORMER EAGLE 5A

Kimley»Horn © 2021 KIMLEY-HORN AND ASSOCIATES, INC. 4001 WILSON DRIVE, SUITE 300 WARRENER, I. E. 60069 PHONE: (848) 448-6655 WWW.KH-BY-HORN.COM	USER NAME =	DESIGNED -	REVISED -	STATE OF ILLINOIS DEPARTMENT OF TRANSPORTATION	SCHEDULE OF QUANTITIES IL 64 (NORTH AVE) AND TERESA LN/MENARDS ENTR				F.A.P. RTE.	SECTION	COUNTY	TOTAL SHEETS	SHEET NO.
		DRAWN -	REVISED -		307	2020-263-SUR, SW&TS	DUPAGE	529	137				
	PLOT SCALE =	CHECKED -	REVISED -		CONTRACT NO. 62N33								
	PLOT DATE =	DATE -	REVISED -		SCALE: N.T.S.	SHEET	OF	SHEETS	STA.	TO STA.			

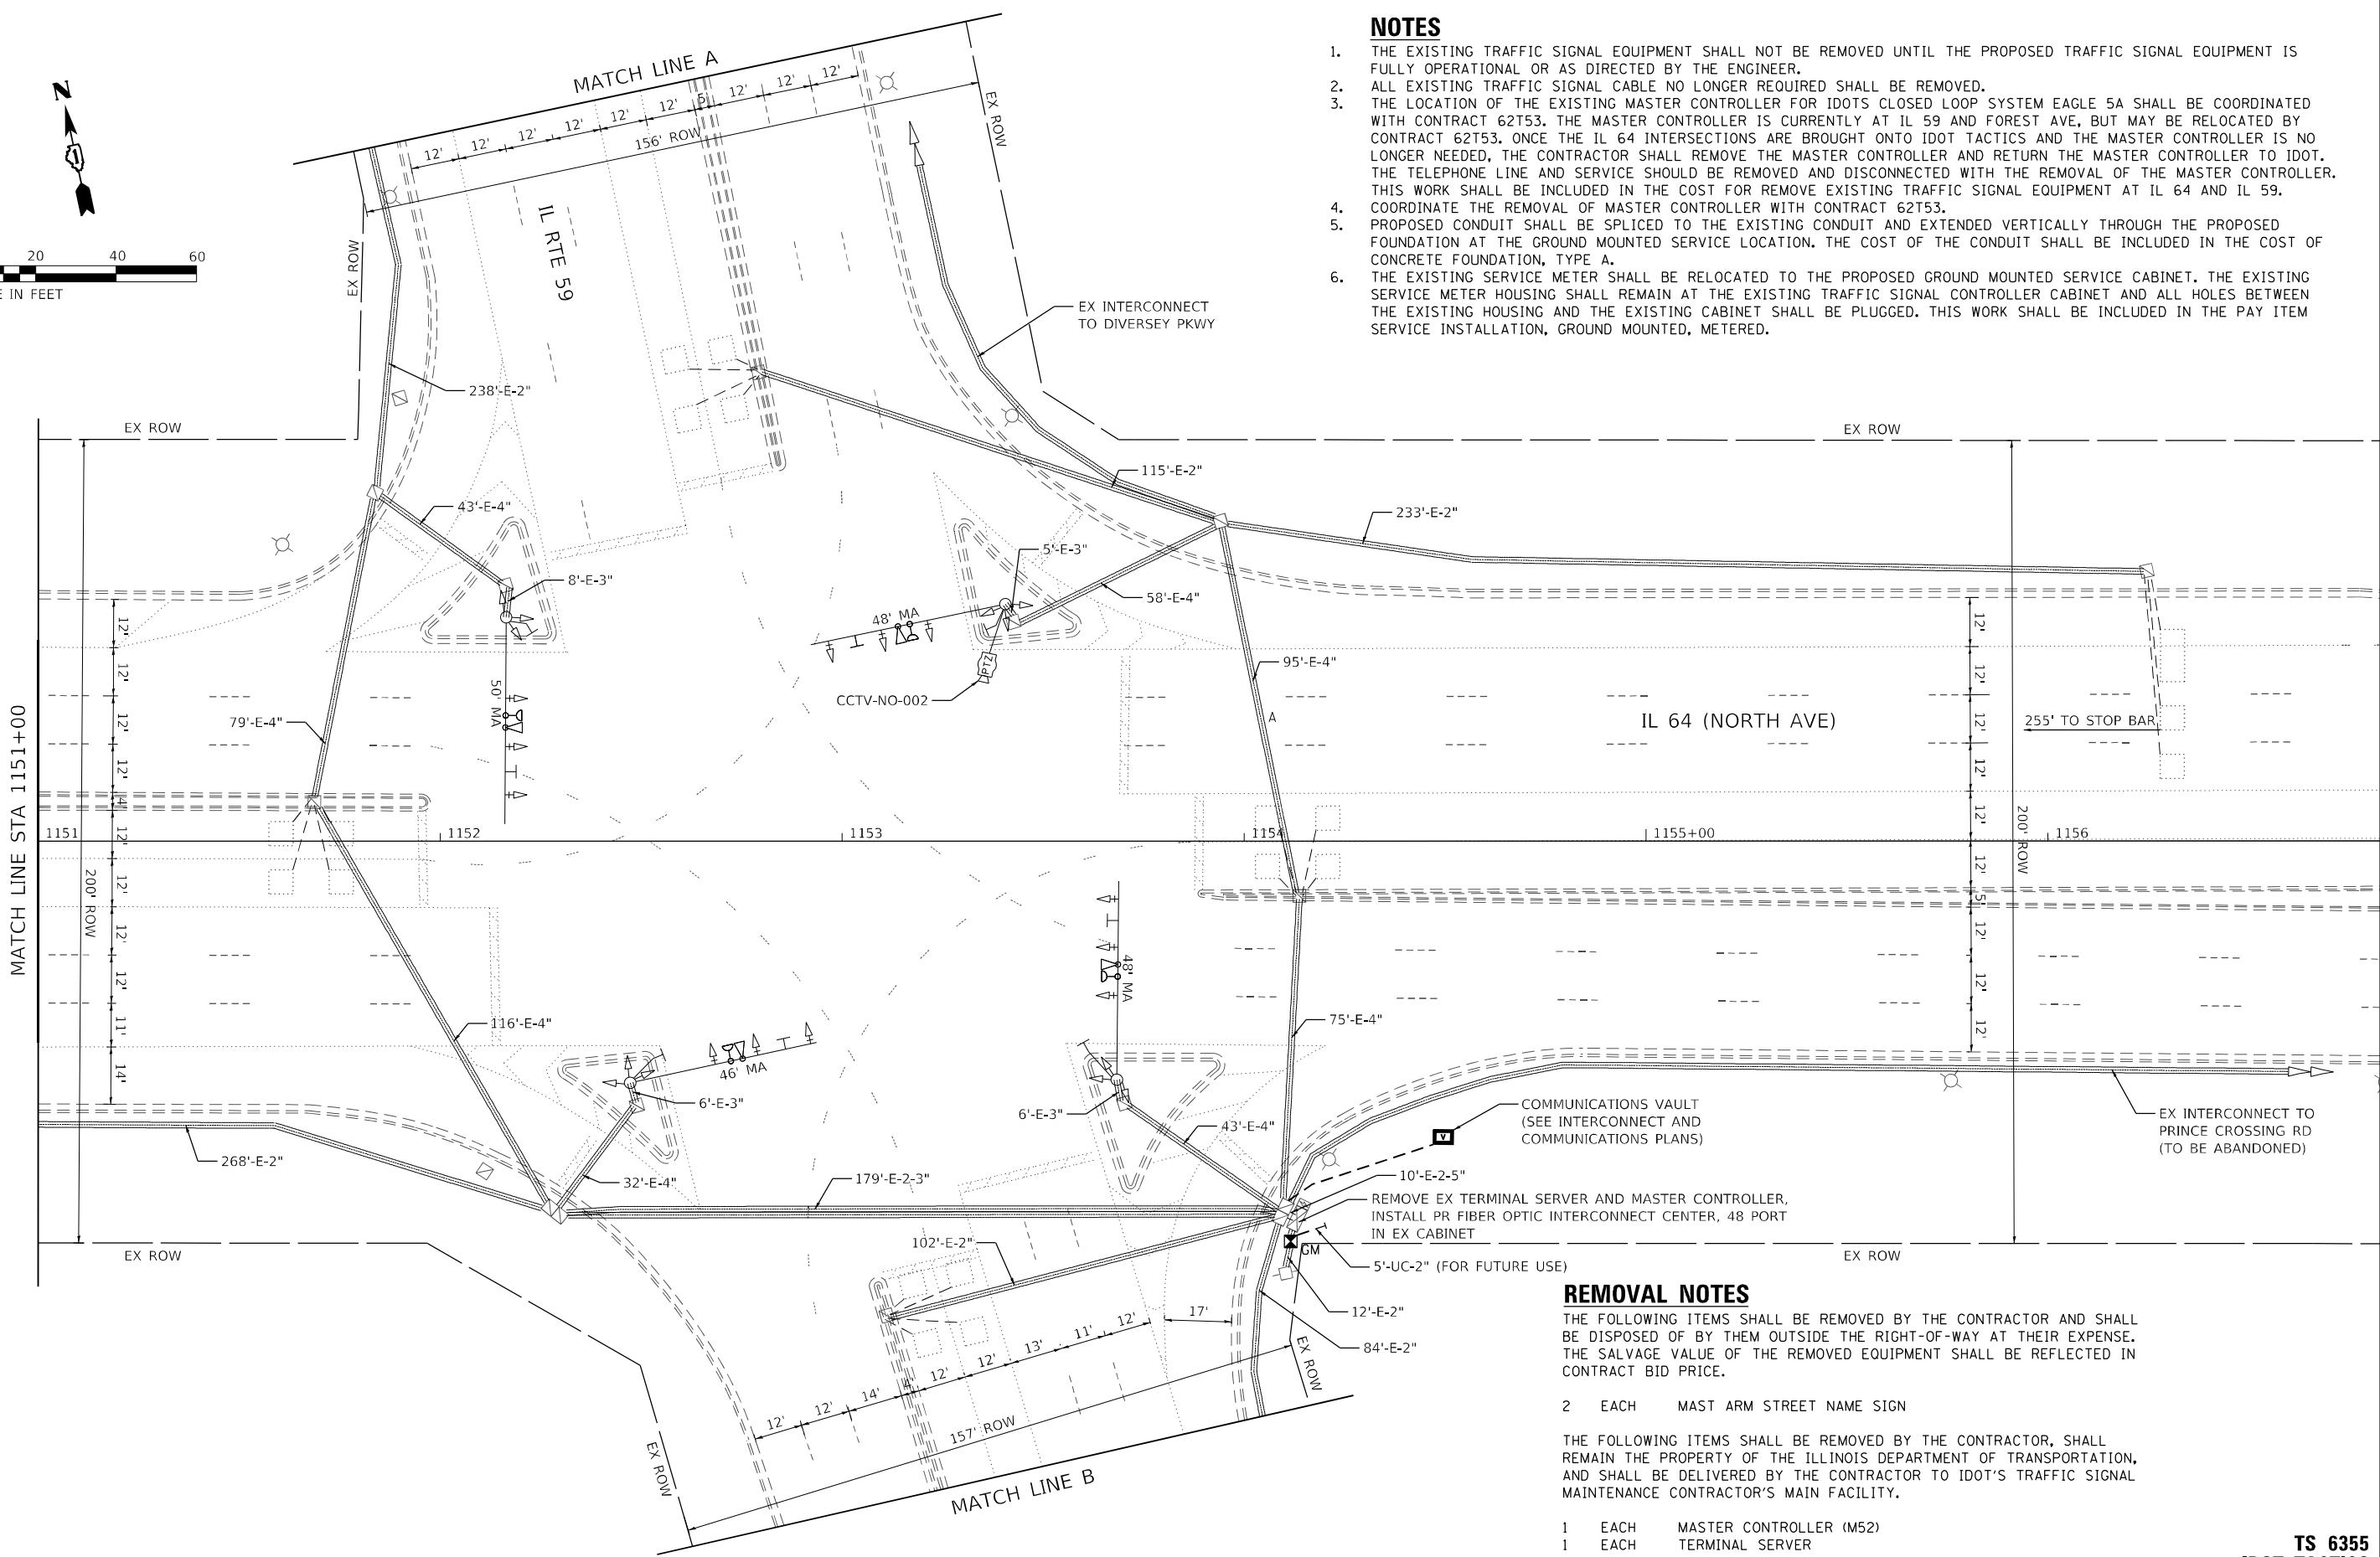

NOTES

1. THE EXISTING TRAFFIC SIGNAL EQUIPMENT SHALL NOT BE REMOVED UNTIL THE PROPOSED TRAFFIC SIGNAL EQUIPMENT IS FULLY OPERATIONAL OR AS DIRECTED BY THE ENGINEER.
2. ALL EXISTING TRAFFIC SIGNAL CABLE NO LONGER REQUIRED SHALL BE REMOVED.
3. THE LOCATION OF THE EXISTING MASTER CONTROLLER FOR IDOT'S CLOSED LOOP SYSTEM EAGLE 5A SHALL BE COORDINATED WITH CONTRACT 62T53. THE MASTER CONTROLLER IS CURRENTLY AT IL 59 AND FOREST AVE, BUT MAY BE RELOCATED BY CONTRACT 62T53. ONCE THE IL 64 INTERSECTIONS ARE BROUGHT ONTO IDOT TACTICS AND THE MASTER CONTROLLER IS NO LONGER NEEDED, THE CONTRACTOR SHALL REMOVE THE MASTER CONTROLLER AND RETURN THE MASTER CONTROLLER TO IDOT. THE TELEPHONE LINE AND SERVICE SHOULD BE REMOVED AND DISCONNECTED WITH THE REMOVAL OF THE MASTER CONTROLLER. THIS WORK SHALL BE INCLUDED IN THE COST FOR REMOVE EXISTING TRAFFIC SIGNAL EQUIPMENT AT IL 64 AND IL 59.
4. COORDINATE THE REMOVAL OF MASTER CONTROLLER WITH CONTRACT 62T53.
5. PROPOSED CONDUIT SHALL BE SPLICED TO THE EXISTING CONDUIT AND EXTENDED VERTICALLY THROUGH THE PROPOSED FOUNDATION AT THE GROUND MOUNTED SERVICE LOCATION. THE COST OF THE CONDUIT SHALL BE INCLUDED IN THE COST OF CONCRETE FOUNDATION, TYPE A.
6. THE EXISTING SERVICE METER SHALL BE RELOCATED TO THE PROPOSED GROUND MOUNTED SERVICE CABINET. THE EXISTING SERVICE METER HOUSING SHALL REMAIN AT THE EXISTING TRAFFIC SIGNAL CONTROLLER CABINET AND ALL HOLES BETWEEN THE EXISTING HOUSING AND THE EXISTING CABINET SHALL BE PLUGGED. THIS WORK SHALL BE INCLUDED IN THE PAY ITEM SERVICE INSTALLATION, GROUND MOUNTED, METERED.

REMOVAL NOTES

THE FOLLOWING ITEMS SHALL BE REMOVED BY THE CONTRACTOR AND SHALL BE DISPOSED OF BY THEM OUTSIDE THE RIGHT-OF-WAY AT THEIR EXPENSE. THE SALVAGE VALUE OF THE REMOVED EQUIPMENT SHALL BE REFLECTED IN CONTRACT BID PRICE.

- 2 EACH MAST ARM STREET NAME SIGN
- THE FOLLOWING ITEMS SHALL BE REMOVED BY THE CONTRACTOR, SHALL REMAIN THE PROPERTY OF THE ILLINOIS DEPARTMENT OF TRANSPORTATION, AND SHALL BE DELIVERED BY THE CONTRACTOR TO IDOT'S TRAFFIC SIGNAL MAINTENANCE CONTRACTOR'S MAIN FACILITY.
- 1 EACH MASTER CONTROLLER (M52)
1 EACH TERMINAL SERVER

TS 6355
IDOT TACTICS
FORMER EAGLE 5A

MODEL: Default
FILE: \\uslpc-prod\h-pw-bentley.com\h-pw-d\1\Documents\01 Active Projects\IMW-CIS-680950\00 - IL 64\Phase II\2 Design\CAD\Plan_Sheets\Signal\West_Corridor_Signals\01081714-IL-Rte-35_KIM.dgn

KimleyHorn

© 2021 KIMLEY-HORN AND ASSOCIATES, INC.
4001 HWY 10 ROAD, SUITE 600
WARREN, IL 60555
PHONE: 815.447.4555
WWW.KIMLEY-HORN.COM

USER NAME =	DESIGNED -	REVISED -
	DRAWN -	REVISED -
PLOT SCALE =	CHECKED -	REVISED -
PLOT DATE =	DATE -	REVISED -


STATE OF ILLINOIS
DEPARTMENT OF TRANSPORTATION

TRAFFIC SIGNAL MODIFICATION PLAN (SHEET 1 OF 2)
IL 64 (NORTH AVE) AND IL RTE 59

SCALE: 1" = 20' SHEET OF SHEETS STA. TO STA.

F.A.P. RTE.	SECTION	COUNTY	TOTAL SHEETS	SHEET NO.
307	2020-263-SUR, SW&TS	DUPAGE	529	138
				CONTRACT NO. 62N33
		ILLINOIS	FED. AID PROJECT	

EXISTING AND PROPOSED
CONTROLLER SEQUENCE

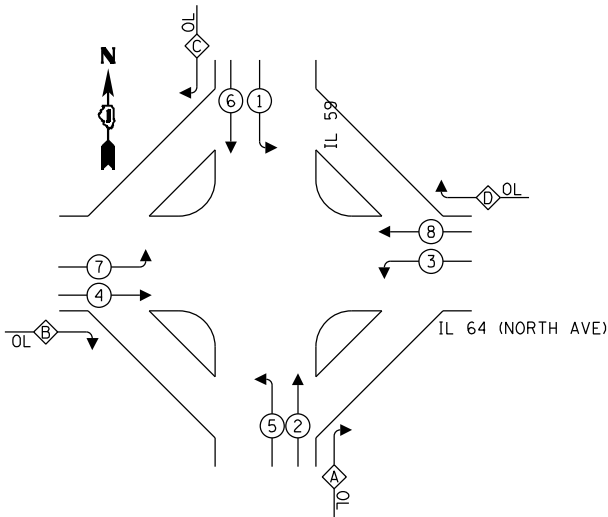


LEGEND:

- ← (⊙) ← PROTECTED PHASE
← (⊙) - PROTECTED/PERMITTED PHASE
← (⊙) → PEDESTRIAN PHASE
← (⊙) OL OVERLAP

OVERLAP LETTER		PERMISSIVE PHASE		PROTECTED PHASE
A	=	2	+	3
B	=	4	+	5
C	=	6	+	7
D	=	8	+	1

EXISTING AND PROPOSED EMERGENCY
VEHICLE PREEMPTION SEQUENCE

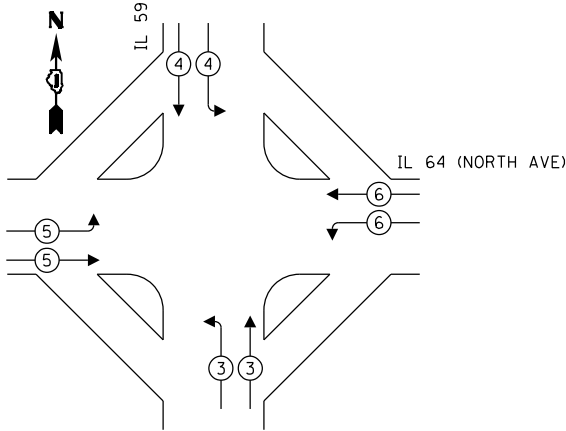

TRAFFIC SIGNAL
ELECTRICAL SERVICE REQUIREMENTS

TYPE	QUANTITY	UNIT WATTAGE	TOTAL WATTAGE
SIGNAL HEAD 1 OR 3-SECTION	16	11	176
4-SECTION	-	14	-
5-SECTION	8	13	104
PROGRAMMABLE 3-SECTION	-	22	-
4-SECTION	-	32	-
5-SECTION	-	28	-
PEDESTRIAN SIGNAL	-	15	-
CONTROLLER	1	150	150
MASTER CONTROLLER	-	100	-
UPS	1	25	25
DETECTION RADAR OR VIDEO	-	20	-
BLANK-OUT SIGN	-	25	-
NETWORK SWITCH II OR III	1	35	35
CELLULAR MODEM	-	15	-
PTZ	1	75	75
TOTAL UPS SIZING		565	
UPS CHARGING	1	225	225
BATTERY HEATER MAT	1	180	180
CABINET HEATER	1	200	200
FLASHER	-	15	-
LED STREET NAME SIGN	-	120	-
LUMINAIRE	-	240	-
TOTAL SERVICE WIRE SIZING		1170	

ENERGY COSTS TO:
ILLINOIS DEPARTMENT OF TRANSPORTATION
201 W CENTER CT
SCHAUMBURG, IL 60196

ENERGY SUPPLY: CONTACT: ANTONIO RIOS
COMPANY: COMED
PHONE: (630) 696-6855
ACCOUNT NUMBER: 05631-53211

LEGEND:

L = LED LAMP MODULE REPLACEMENT

STATE OF ILLINOIS
DEPARTMENT OF TRANSPORTATION

CABLE PLAN
(NOT TO SCALE)

CABLE PLAN, PHASE DESIGNATION DIAGRAM AND
EMERGENCY VEHICLE PREEMPTION SEQUENCE
IL 64 (NORTH AVE) AND IL RTE 59

SCALE: N.T.S. SHEET OF SHEETS STA. TO STA.

EX INTERCONNECT
TO DIVERSEY PKWY/
7TH AVE

EX TRACER CABLE

IL 64 (NORTH AVE)

EX INTERCONNECT
TO PRINCE
CROSSING RD (TO
BE ABANDONED)

EX TRACER CABLE
(TO BE ABANDONED)

PR LATERAL AND
TRACER CABLE
(SEE
COMMUNICATION
PLANS)

TS 6355
IDOT TACTICS
FORMER EAGLE 5A

F.A.P. RTE.	SECTION	COUNTY	TOTAL SHEETS	SHEET NO.
307	2020-263-SUR, SW&TS	DUPAGE	529	140
CONTRACT NO. 62N33				
ILLINOIS FED. AID PROJECT				

SIGN PANEL – TYPE 2

ALL DIMENSIONS ARE IN INCHES UNLESS OTHERWISE NOTED



DESIGN SERIES	AREA (SQ FT)	SIGN PANEL TYPE	SHEETING TYPE	QTY. REQUIRED
D	12.5	2	ZZ	2

SCHEDULE OF QUANTITIES

ITEM DESCRIPTION	UNIT	QUANTITY
SIGN PANEL - TYPE 2	SQ FT	25
UNDERGROUND CONDUIT, GALVANIZED STEEL, 2" DIA.	FOOT	5
MAINTENANCE OF EXISTING TRAFFIC SIGNAL INSTALLATION	EACH	1
ELECTRIC CABLE IN CONDUIT, SERVICE, NO. 6 2 C	FOOT	40
ELECTRIC CABLE IN CONDUIT, EQUIPMENT GROUNDING CONDUCTOR, NO. 6 1C	FOOT	40
CONCRETE FOUNDATION, TYPE A	FOOT	4
REMOVE EXISTING TRAFFIC SIGNAL EQUIPMENT	EACH	1
LED LAMP MODULE REPLACEMENT	EACH	80
SERVICE INSTALLATION, GROUND MOUNTED, METERED	EACH	1
LAYER II (DATALINK) SWITCH	EACH	1
TERMINATE FIBER IN CABINET	EACH	12
UPGRADE EXISTING CONTROLLER TO NTCIP SPECIAL	EACH	1
FIBER OPTIC INTERCONNECT CENTER, 48 PORT	EACH	1
LED SIGNAL FACE, LENS COVER	EACH	24

TS 6355
IDOT TACTICS
FORMER EAGLE 5A

Model: Default
File Name: p:\utp\pvt\bartley.com\ktp\p4\1\Documents\01 Active Projects\MW\CL-S-16895\100 - IL 64\Phase II\2 Design\CAD\Plan Sheets\Sign\InWest Corridor_Signs\BID 108171\4-rt-40_K4A.dgn



© 2023 KIMLEY-HORN AND ASSOCIATES, INC.
4001 KIMLEY-HORN ROAD, SUITE 600
WARREN, IL 60555
PHONE: 815.447.4555
WWW.KIMLEY-HORN.COM

USER NAME =	DESIGNED -	REVISED -
	DRAWN -	REVISED -
PLOT SCALE =	CHECKED -	REVISED -
PLOT DATE =	DATE -	REVISED -

STATE OF ILLINOIS
DEPARTMENT OF TRANSPORTATION

SCHEDULE OF QUANTITIES			
IL 64 (NORTH AVE) AND IL RTE 59			
SCALE: N.T.S.	SHEET	OF	SHEETS
STA.		TO STA.	

F.A.P. RTE.	SECTION	COUNTY	TOTAL SHEETS	SHEET NO.
307	2020-263-SUR,SW&TS	DUPAGE	529	141
CONTRACT NO. 62N33				
		ILLINOIS	FED. AID PROJECT	

NOTES

1. THE EXISTING TRAFFIC SIGNAL EQUIPMENT SHALL NOT BE REMOVED UNTIL THE PROPOSED TRAFFIC SIGNAL EQUIPMENT IS FULLY OPERATIONAL OR AS DIRECTED BY THE ENGINEER.
2. ALL EXISTING TRAFFIC SIGNAL CABLE NO LONGER REQUIRED SHALL BE REMOVED.


REMOVAL NOTES

THE FOLLOWING ITEMS SHALL BE REMOVED BY THE CONTRACTOR AND SHALL BE DISPOSED OF BY THEM OUTSIDE THE RIGHT-OF-WAY AT THEIR EXPENSE. THE SALVAGE VALUE OF THE REMOVED EQUIPMENT SHALL BE REFLECTED IN CONTRACT BID PRICE.

- 16 EACH 3-SECTION SIGNAL HEAD
4 EACH 5-SECTION SIGNAL HEAD
10 EACH TRAFFIC SIGNAL BACKPLATES
2 EACH MAST ARM AND ASSEMBLY AND POLE
4 EACH TRAFFIC SIGNAL POST
3 EACH STREET NAME SIGN PANEL
1 EACH CONTROLLER (M41)

THE FOLLOWING ITEMS SHALL BE REMOVED BY THE CONTRACTOR, SHALL REMAIN THE PROPERTY OF THE ILLINOIS DEPARTMENT OF TRANSPORTATION, AND SHALL BE DELIVERED BY THE CONTRACTOR TO IDOT'S TRAFFIC SIGNAL MAINTENANCE CONTRACTOR'S MAIN FACILITY.

- 1 EACH VIDEO VEHICLE DETECTION SYSTEM

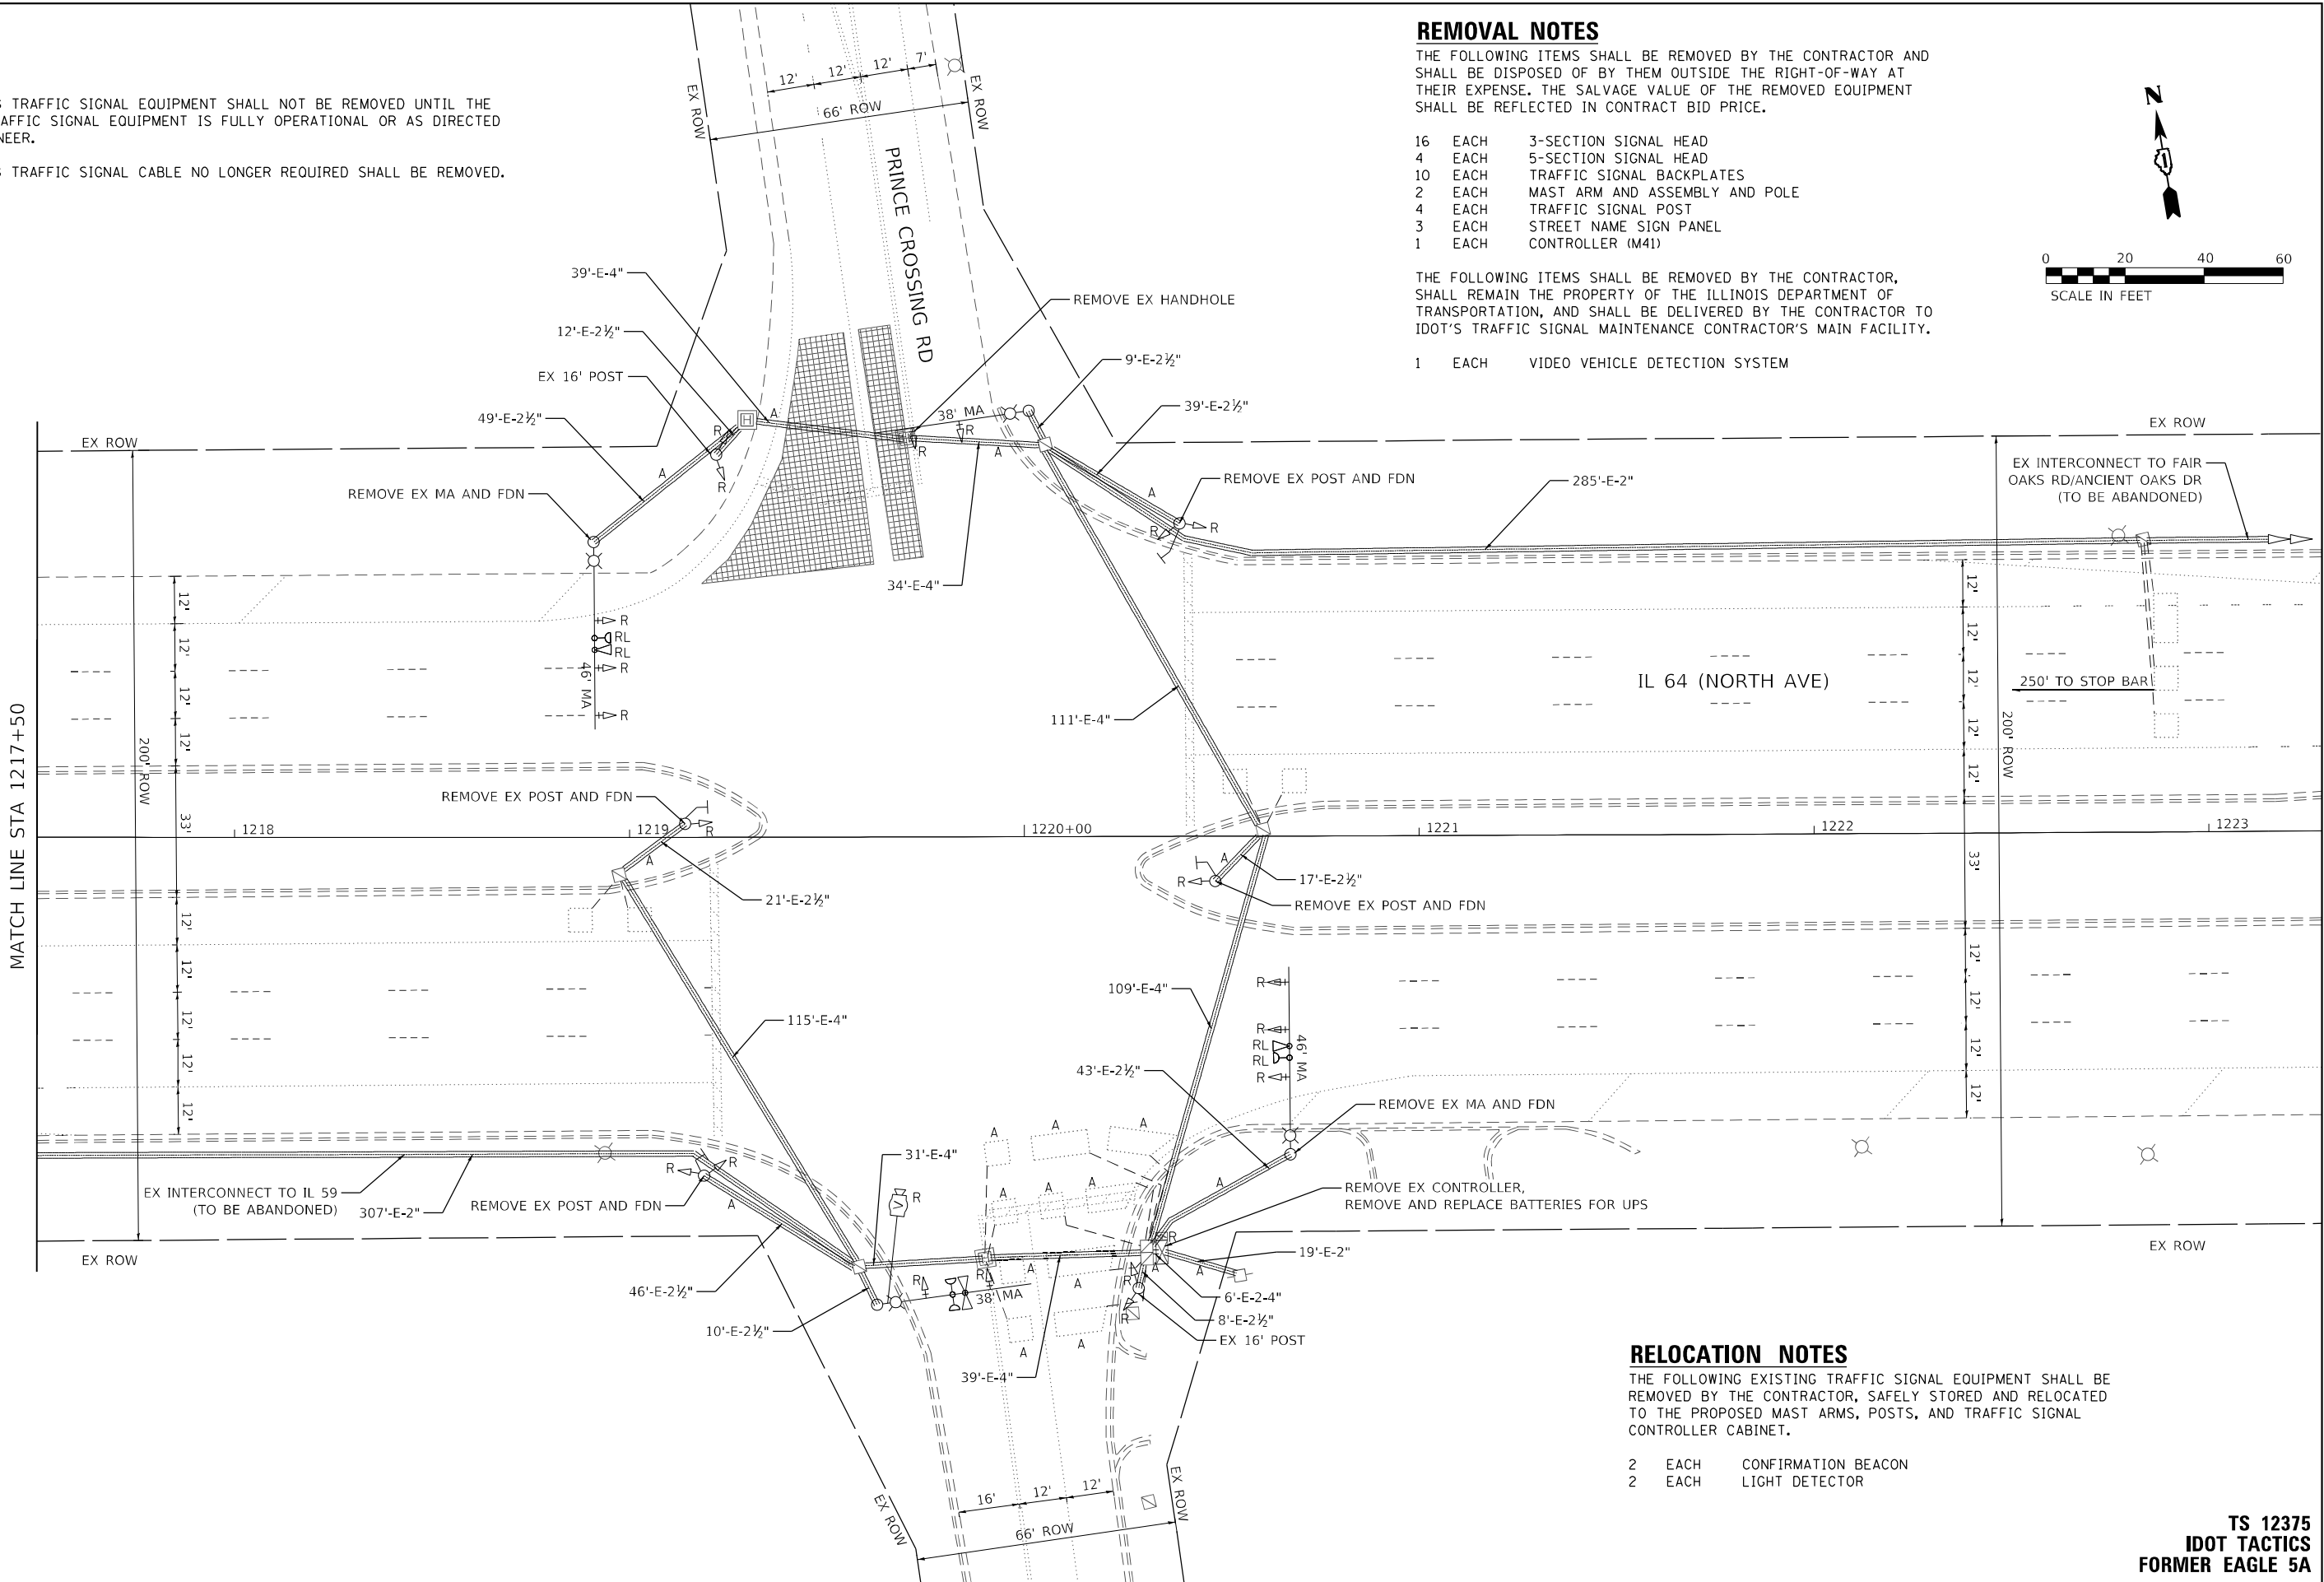

RELOCATION NOTES

THE FOLLOWING EXISTING TRAFFIC SIGNAL EQUIPMENT SHALL BE REMOVED BY THE CONTRACTOR, SAFELY STORED AND RELOCATED TO THE PROPOSED MAST ARMS, POSTS, AND TRAFFIC SIGNAL CONTROLLER CABINET.

- 2 EACH CONFIRMATION BEACON
2 EACH LIGHT DETECTOR

TS 12375
IDOT TACTICS
FORMER EAGLE 5A



© 2023 KIMLEY-HORN AND ASSOCIATES, INC.
4001 WILMINGTON ROAD, SUITE 600
WARREN, IL 60555
PHONE: (847) 455-4555
WWW.KIMLEY-HORN.COM



USER NAME =	DESIGNED -	REVISED -
	DRAWN -	REVISED -
PLOT SCALE =	CHECKED -	REVISED -
PLOT DATE =	DATE -	REVISED -

STATE OF ILLINOIS
DEPARTMENT OF TRANSPORTATION

TRAFFIC SIGNAL EQUIPMENT REMOVAL PLAN
IL 64 (NORTH AVE) AND PRINCE CROSSING RD

SCALE: 1" = 20' SHEET OF SHEETS STA. TO STA.

F.A.P. RTE.	SECTION	COUNTY	TOTAL SHEETS	SHEET NO.
307	2020-263-SUR, SW&TS	DUPAGE	529	142
CONTRACT NO. 62N33				
ILLINOIS FED. AID PROJECT				

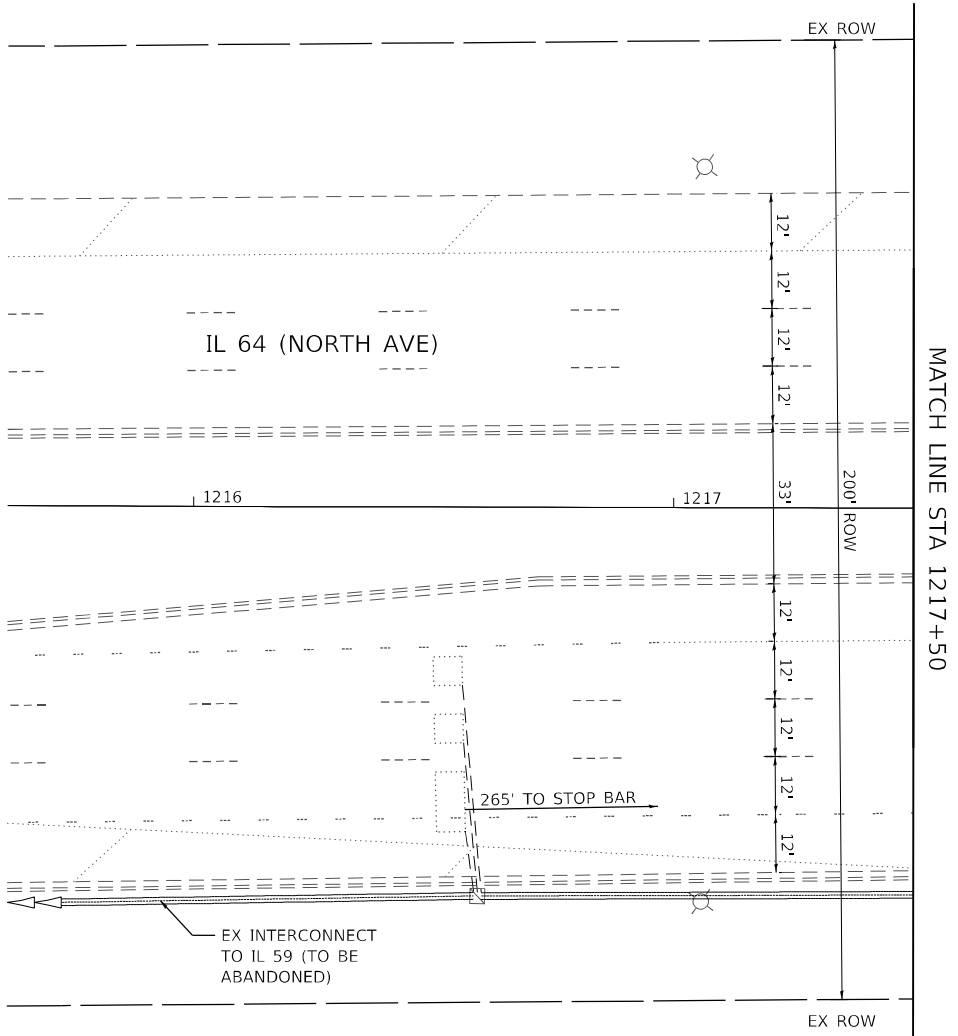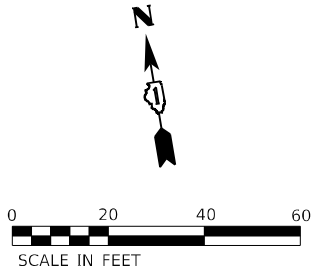

MODEL: Default
FILE NAME: p:\sub-pw\bartley.com\k-h-pw-d1\Documents\01 Active Projects\MW\CHS-168950\00 - IL 64\Phase II\2 Design\CAD\Plan Sheets\Signal\West Corridor Signal\01081714-IL-64-2_KH.dgn



USER NAME =	DESIGNED -	REVISED -
	DRAWN -	REVISED -
PLOT SCALE =	CHECKED -	REVISED -
PLOT DATE =	DATE -	REVISED -



STATE OF ILLINOIS
DEPARTMENT OF TRANSPORTATION

TRAFFIC SIGNAL EQUIPMENT REMOVAL PLAN
IL 64 (NORTH AVE) AND PRINCE CROSSING RD

SCALE: 1" = 20' SHEET OF SHEETS STA. TO STA.

F.A.P. RTE.	SECTION	COUNTY	TOTAL SHEETS	SHEET NO.
307	2020-263-SUR,SW&TS	DUPAGE	529	143
CONTRACT NO. 62N33				
		ILLINOIS	FED. AID PROJECT	

TS 12375
IDOT TACTICS
FORMER EAGLE 5A

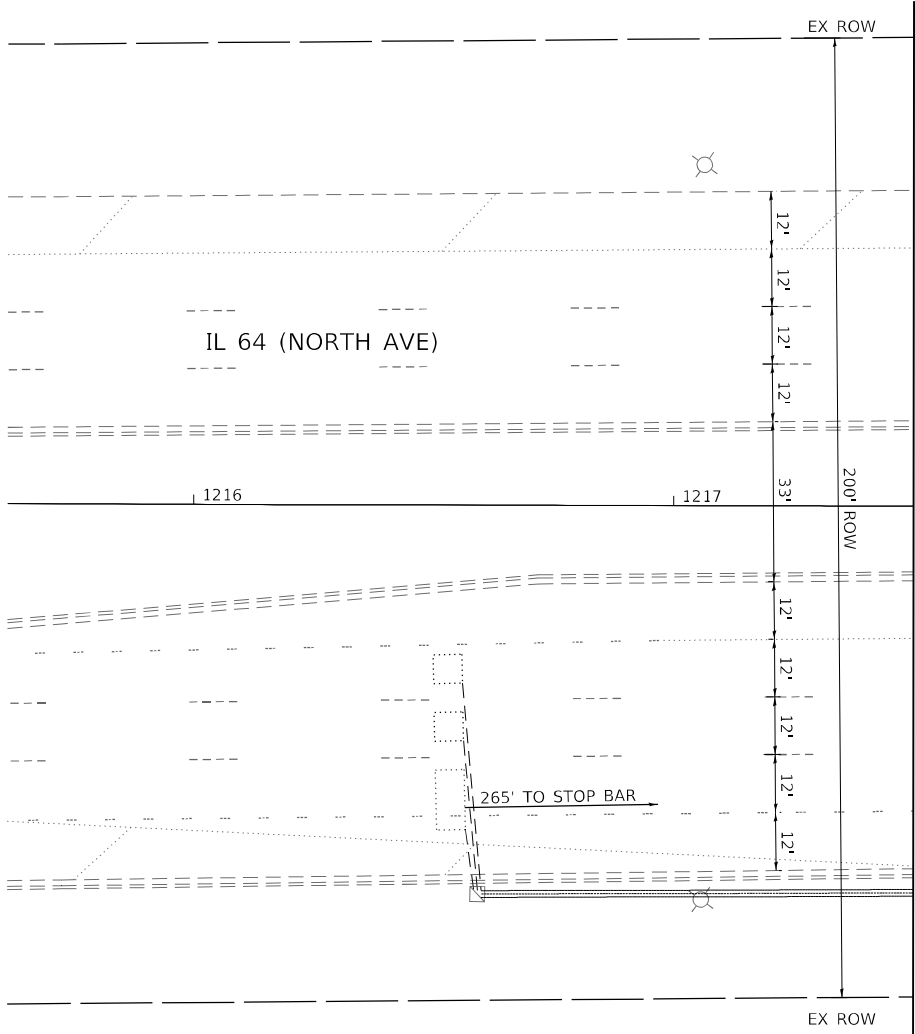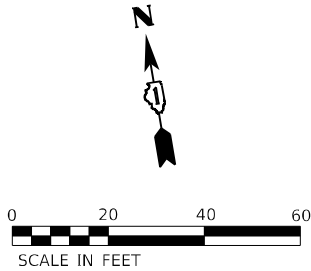

MODEL: Default
FILE NAME: p:\sub-pw\bartley.com\k-h-pw-d1\Documents\01 Active Projects\MW\CHS-16895\100 - IL 64\Phase II\2 Design\CAD\Plan Sheets\Signal\West Corridor Signal\01081714-IL-64-K4A.dgn



USER NAME =	DESIGNED -	REVISED -
	DRAWN -	REVISED -
PLOT SCALE =	CHECKED -	REVISED -
PLOT DATE =	DATE -	REVISED -

STATE OF ILLINOIS
DEPARTMENT OF TRANSPORTATION

TRAFFIC SIGNAL MODERNIZATION PLAN
IL 64 (NORTH AVE) AND PRINCE CROSSING RD

SCALE: 1" = 20' SHEET OF SHEETS STA. TO STA.

F.A.P. RTE.	SECTION	COUNTY	TOTAL SHEETS	SHEET NO.
307	2020-263-SUR,SW&TS	DUPAGE	529	145
CONTRACT NO. 62N33				
		ILLINOIS	FED. AID PROJECT	

TS 12375
IDOT TACTICS
FORMER EAGLE 5A

Diagram illustrating a four-way intersection with traffic flow and lane markings:

- Northbound (Prince Crossing Rd):** Lanes 4 and 7. Lane 4 is marked with a diamond-shaped sign with 'OL'.
- Southbound (IL 64 (North Ave)):** Lanes 3 and 8.
- Eastbound (IL 64 (North Ave)):** Lanes 6 and 1. Lane 6 is marked with a diamond-shaped sign with 'OL'.
- Westbound (IL 64 (North Ave)):** Lanes 5 and 2.
- Signage:** A diamond-shaped sign with 'OL' is shown on the eastbound side of IL 64.
- Legend:** OVERLAP LETTER (A, C).

 PROTECTED PHASE
 PROTECTED/PERMITTED PHASE
 PEDESTRIAN PHASE
 OVERLAP

TYPE	QUANTITY	UNIT WATTAGE	TOTAL WATTAGE
SIGNAL HEAD 1 OR 3-SECTION	14	11	154
4-SECTION	-	14	-
5-SECTION	8	13	104
PROGRAMMABLE 3-SECTION	-	22	-
4-SECTION	-	32	-
5-SECTION	-	28	-
PEDESTRIAN SIGNAL	-	15	-
CONTROLLER	1	150	150
MASTER CONTROLLER	-	100	-
UPS	1	25	25
DETECTION VIDEO	2	20	40
BLANK-OUT SIGN	-	25	-
NETWORK SWITCH LAYER II OR III	1	35	35
CELLULAR MODEM	-	15	-
PTZ	1	75	75
TOTAL UPS SIZING			583
UPS CHARGING	1	225	225
BATTERY HEATER MAT	1	180	180
CABINET HEATER	1	200	200
FLASHER	-	15	-
LED STREET NAME SIGN	-	120	-
LUMINAIRE	-	240	-

1. EXISTING CABLE SLACK SHALL BE USED TO INSTALL PROPOSED SIGNAL HEADS AND EVP DETECTOR AT THEIR NEW LOCATION ALONG THE EXISTING MAST ARM.

ENERGY SUPPLY: COMPANY: COMED
PHONE: (866) 639-3532
ACCOUNT NUMBER: 73470-49055

**PRINCE
CROSSING ROAD**

SEE NOTE 1

M

EX INTERCONNECT TO FAIR OAKS RD / ANCIENT OAKS DR (TO BE ABANDONED)

24F

EX TRACER CABLE (TO BE ABANDONED)

R Y G Y G

V

7

5

1

2

2

2

M

7

G Y G

5

2

IL 64 (NORTH AVE)

RL RL

3#20

3

5

5

5

7

ONC

P

PR LATERAL AND TRACER CABLE (SEE COMMUNICATION PLANS)

24SM

1

PR CONTROLLER IN EX CABINET

C

1#6

2#6

S

GM


2#6

S

F.A.P. RTE.	SECTION	COUNTY	TOTAL SHEETS	SHEET NO.
307	2020-263-SUR,SW&TS	DUPAGE	529	146
		CONTRACT NO. 62N33		
ILLINOIS		FED. AID PROJECT		

SIGN PANEL – TYPE 2

ALL DIMENSIONS ARE IN INCHES UNLESS OTHERWISE NOTED

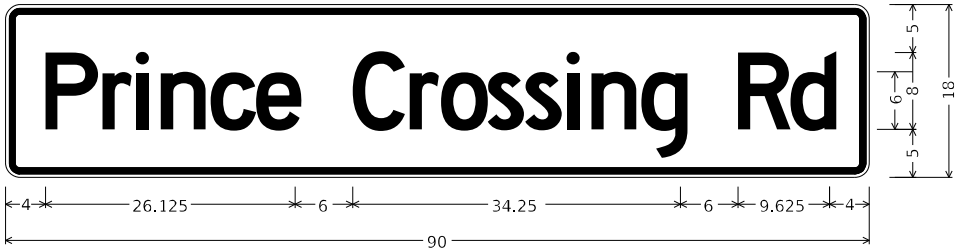

DESIGN SERIES	AREA (SQ FT)	SIGN PANEL TYPE	SHEETING TYPE	QTY. REQUIRED
C	11.25	2	ZZ	2



DESIGN SERIES	AREA (SQ FT)	SIGN PANEL TYPE	SHEETING TYPE	QTY. REQUIRED
D	12.5	2	ZZ	2

SCHEDULE OF QUANTITIES

ITEM DESCRIPTION	UNIT	QUANTITY
SIGN PANEL - TYPE 2	SQ FT	47.5
UNDERGROUND CONDUIT, GALVANIZED STEEL, 2" DIA.	FOOT	5
UNDERGROUND CONDUIT, GALVANIZED STEEL, 3" DIA.	FOOT	172
UNDERGROUND CONDUIT, GALVANIZED STEEL, 4" DIA.	FOOT	410
DOUBLE HANDHOLE	EACH	1
MAINTENANCE OF EXISTING TRAFFIC SIGNAL INSTALLATION	EACH	1
ELECTRIC CABLE IN CONDUIT, SIGNAL NO. 14 3C	FOOT	661
ELECTRIC CABLE IN CONDUIT, SIGNAL NO. 14 5C	FOOT	3215
ELECTRIC CABLE IN CONDUIT, SIGNAL NO. 14 7C	FOOT	1232
ELECTRIC CABLE IN CONDUIT, SERVICE, NO. 6 2 C	FOOT	31
ELECTRIC CABLE IN CONDUIT, EQUIPMENT GROUNDING CONDUCTOR, NO. 6 1C	FOOT	613
STEEL MAST ARM ASSEMBLY AND POLE, 24 FT.	EACH	1
STEEL MAST ARM ASSEMBLY AND POLE, 32 FT.	EACH	1
STEEL COMBINATION MAST ARM ASSEMBLY AND POLE 64 FT.	EACH	1
STEEL COMBINATION MAST ARM ASSEMBLY AND POLE 66 FT.	EACH	1
CONCRETE FOUNDATION, TYPE A	FOOT	4
CONCRETE FOUNDATION, TYPE E 30-INCH DIAMETER	FOOT	10
CONCRETE FOUNDATION, TYPE E 36-INCH DIAMETER	FOOT	13.5
CONCRETE FOUNDATION, TYPE E 42-INCH DIAMETER	FOOT	46
DRILL EXISTING HANDHOLE	EACH	9
SIGNAL HEAD, LED, 1-FACE, 3-SECTION, MAST-ARM MOUNTED	EACH	12
SIGNAL HEAD, LED, 1-FACE, 3-SECTION, BRACKET MOUNTED	EACH	2
SIGNAL HEAD, LED, 1-FACE, 5-SECTION, BRACKET MOUNTED	EACH	2
SIGNAL HEAD, LED, 1-FACE, 5-SECTION, MAST-ARM MOUNTED	EACH	6
TRAFFIC SIGNAL BACKPLATE, LOUVERED, FORMED PLASTIC	EACH	18
* RELOCATE EXISTING EMERGENCY VEHICLE PRIORITY SYSTEM, DETECTOR UNIT	EACH	2
REMOVE EXISTING TRAFFIC SIGNAL EQUIPMENT	EACH	1
REMOVE EXISTING HANDHOLE	EACH	1
REMOVE EXISTING CONCRETE FOUNDATION	EACH	6
CLOSED CIRCUIT TELEVISION DOME CAMERA, HD	EACH	1
* EMERGENCY VEHICLE PRIORITY SYSTEM LINE SENSOR CABLE, NO. 20 3/C	FOOT	660
OUTDOOR RATED NETWORK CABLE	FOOT	159
SERVICE INSTALLATION, GROUND MOUNTED, METERED	EACH	1
REMOTE CONTROLLED VIDEO SYSTEM	EACH	1
LAYER II (DATALINK) SWITCH	EACH	1
TERMINATE FIBER IN CABINET	EACH	12
TACTICS LICENSE EXPANSION	EACH	1
FULL-ACTUATED CONTROLLER IN EXISTING CABINET	EACH	1
REMOVE AND REPLACE BATTERIES FOR UNINTERUPTABLE POWER SUPPLY, EXTENDED	EACH	1
FIBER OPTIC INTERCONNECT CENTER, 48 PORT	EACH	1
LED SIGNAL FACE, LENS COVER	EACH	22
VIDEO VEHICLE DETECTION SYSTEM, SINGLE APPROACH	EACH	2
CAMERA MOUNTING ASSEMBLY	EACH	1

* - 100% COST TO THE CITY OF WEST CHICAGO

TS 12375
IDOT TACTICS
FORMER EAGLE 5A

MODEL: Default
FILE: \\miller-prod-bentley.com\khp-gp-d1\Documents\01 Active Projects\WW-CIS-68959\00 - IL 64\Phase II\2 Design\CAD\Plan_Sheets\Sign\West_Corridor_Sign\BID\081714-rt-rs-46_KH.dgn



© 2023 KIMLEY-HORN AND ASSOCIATES, INC.
4001 KIMBLE D ROAD, SUITE 600
WARREN, IL 6 0585
PHONE: 815.447.4555
WWW.KIMLEY-HORN.COM

USER NAME =	DESIGNED -	REVISED -
	DRAWN -	REVISED -
PLOT SCALE =	CHECKED -	REVISED -
PLOT DATE =	DATE -	REVISED -

STATE OF ILLINOIS
DEPARTMENT OF TRANSPORTATION

MAST ARM MOUNTED STREET NAME SIGNS AND SCHEDULE OF QUANTITIES IL 64 (NORTH AVE) AND PRINCE CROSSING RD			
SCALE: N.T.S.	SHEET	OF	SHEETS
		STA.	TO STA.

F.A.P. RTE.	SECTION	COUNTY	TOTAL SHEETS	SHEET NO.
307	2020-263-SUR,SW&TS	DUPAGE	529	147
CONTRACT NO. 62N33				
		ILLINOIS	FED. AID PROJECT	

REMOVAL NOTES

THE FOLLOWING ITEMS SHALL BE REMOVED BY THE CONTRACTOR AND SHALL BE DISPOSED OF BY THEM OUTSIDE THE RIGHT-OF-WAY AT THEIR EXPENSE. THE SALVAGE VALUE OF THE REMOVED EQUIPMENT SHALL BE REFLECTED IN CONTRACT BID PRICE.



- 18 EACH SIGNAL HEAD, 1 FACE, 3 SECTION
- 10 EACH TRAFFIC SIGNAL BACKPLATE
- 3 EACH COMBINATION MAST ARM ASSEMBLY AND POLE
- 3 EACH TRAFFIC SIGNAL POST
- 4 EACH STREET NAME SIGN PANEL
- 1 EACH CONTROLLER (M41)
- 1 EACH GROUND MOUNTED SERVICE

THE FOLLOWING ITEMS SHALL BE REMOVED BY THE CONTRACTOR, SHALL REMAIN THE PROPERTY OF THE ILLINIS DEPARTMENT OF TRANSPORTATION, AND SHALL BE DELIVERED BY THE CONTRACTOR TO IDOT'S TRAFFIC SIGNAL MAINTENANCE CONTRACTOR'S MAIN FACILITY.

- 1 EACH VIDEO VEHICLE DETECTION SYSTEM (COMPLETE INTERSECTION)

NOTES

- 1. THE EXISTING TRAFFIC SIGNAL EQUIPMENT SHALL NOT BE REMOVED UNTIL THE PROPOSED TRAFFIC SIGNAL EQUIPMENT IS FULLY OPERATIONAL OR AS DIRECTED BY THE ENGINEER.
- 2. ALL EXISTING TRAFFIC SIGNAL CABLE NO LONGER REQUIRED SHALL BE REMOVED.
- 3. THE ELECTRIC METER SHALL BE RELOCATED FROM THE EXISTING TRAFFIC SIGNAL CABINET TO THE PROPOSED GROUND MOUNTED METERED SERVICE CABINET.

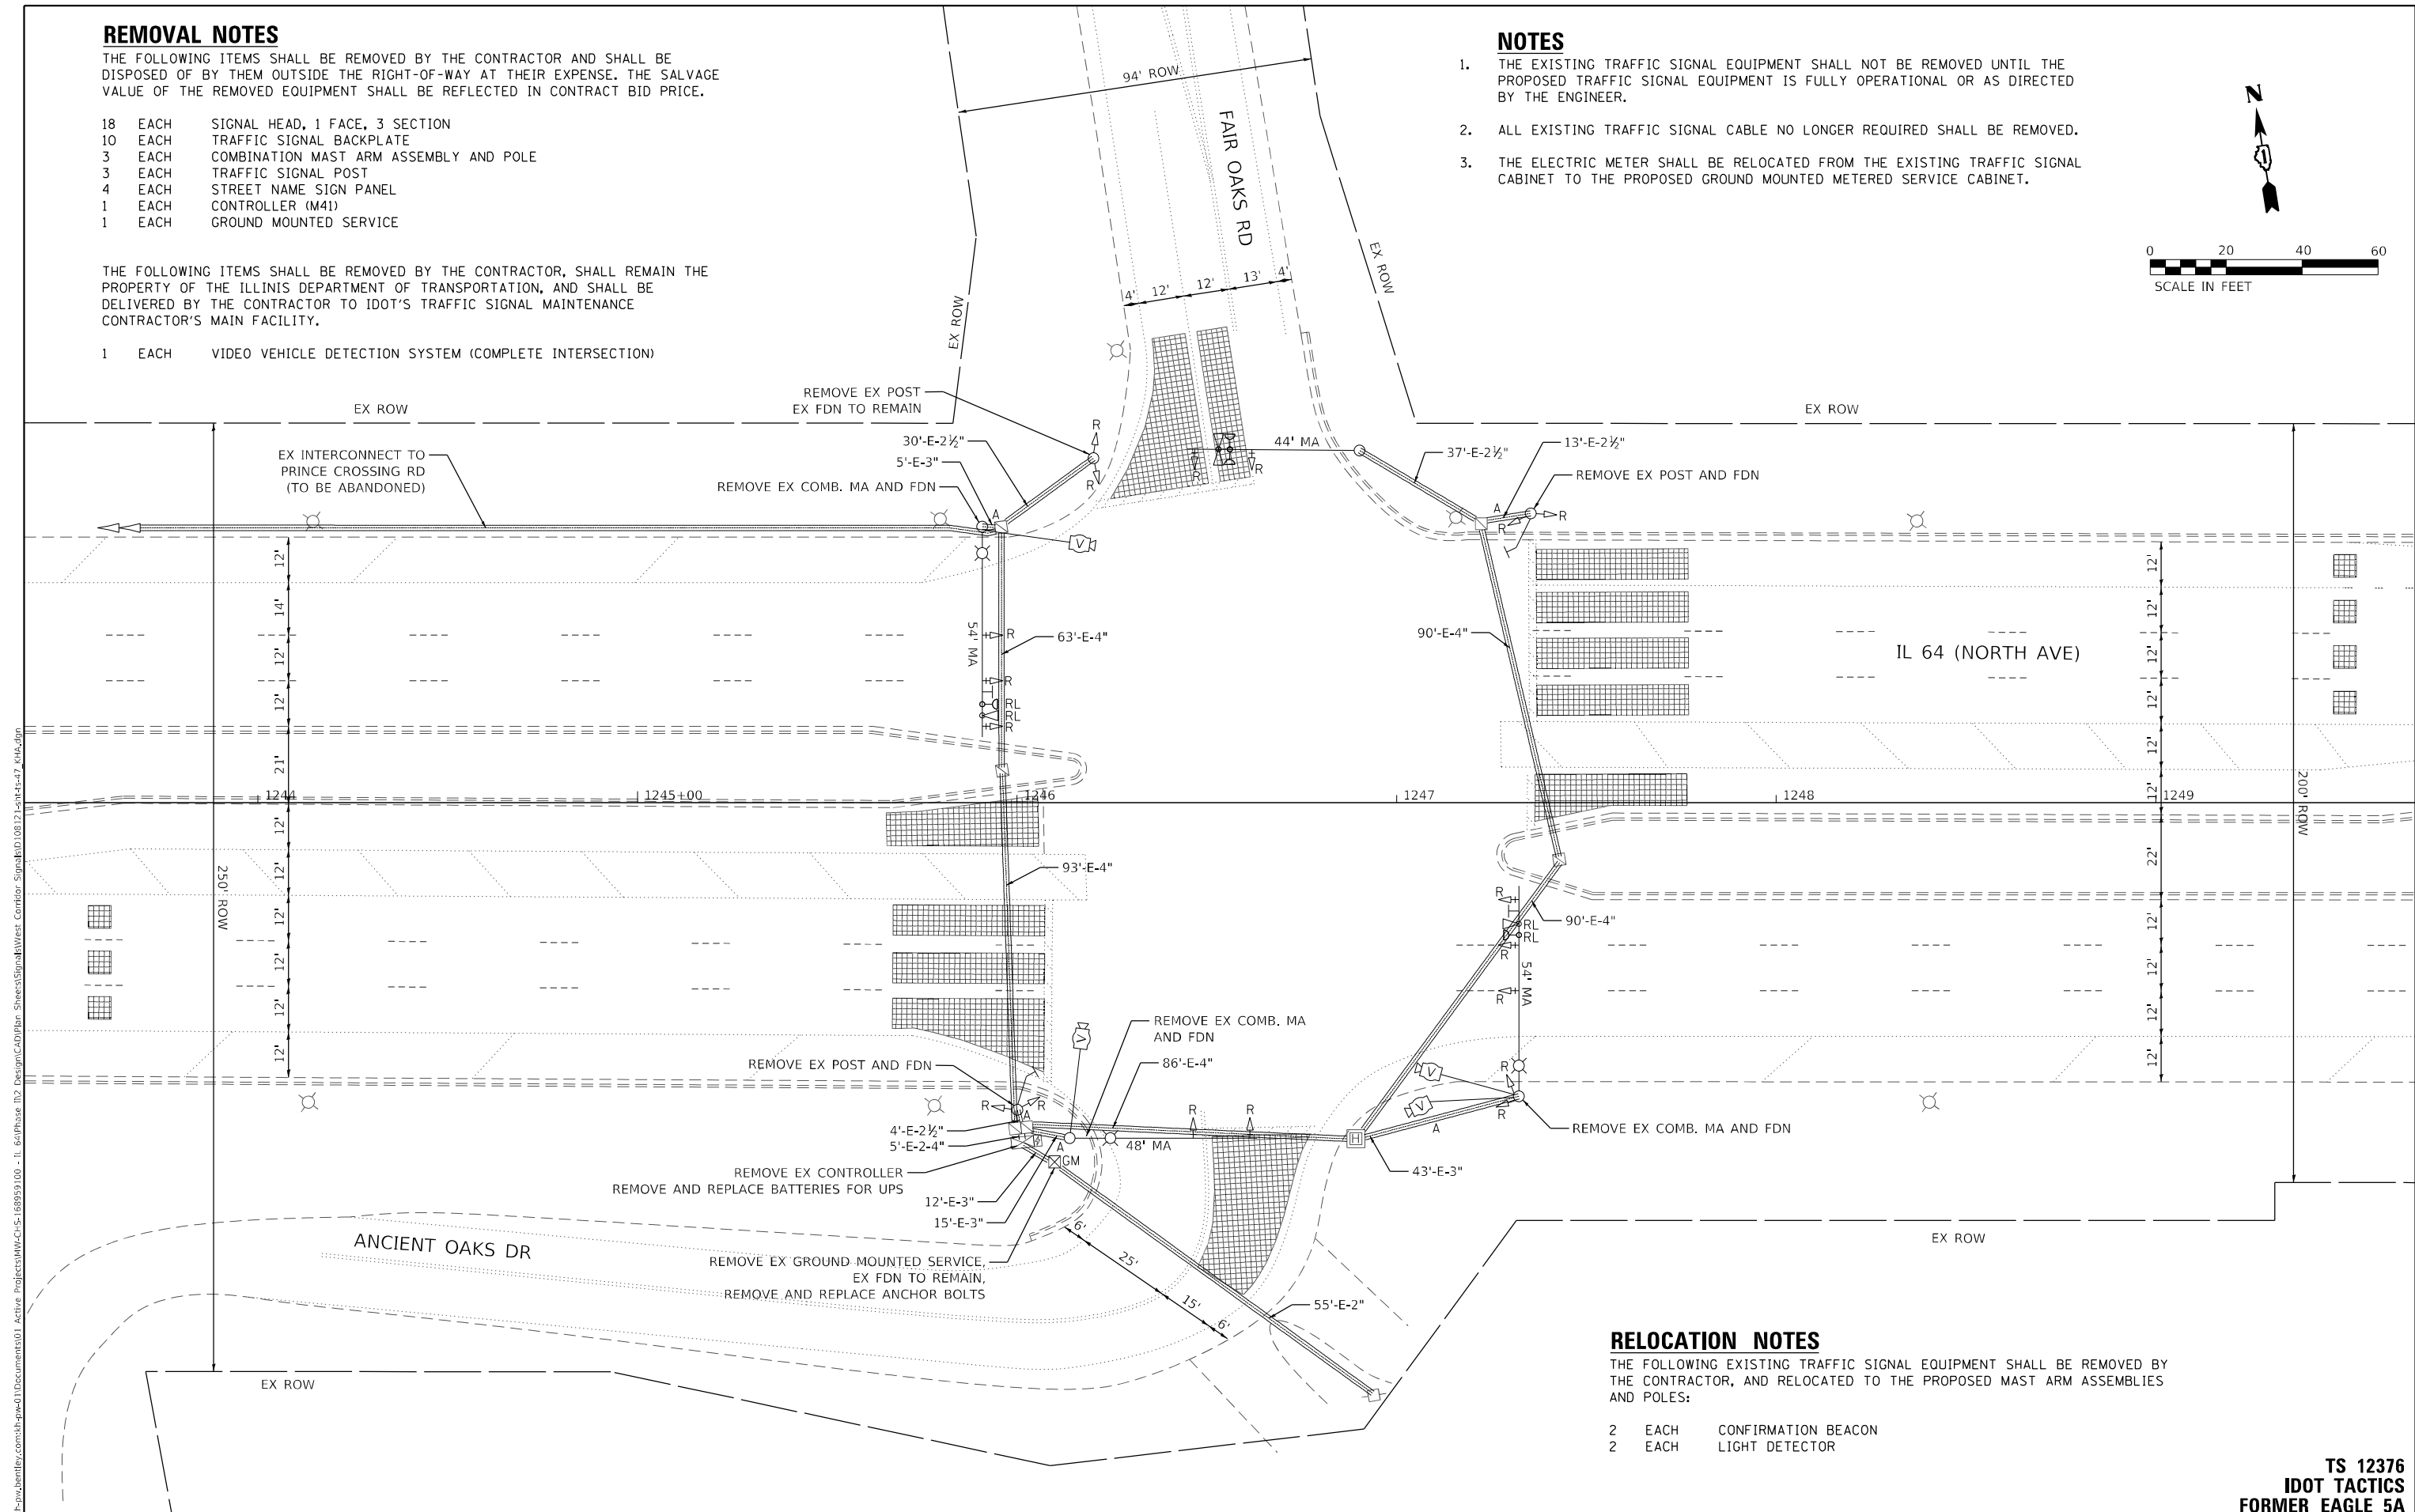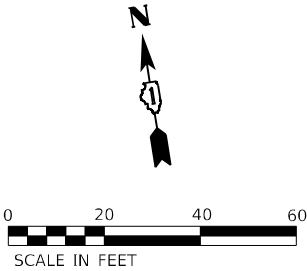

RELOCATION NOTES



THE FOLLOWING EXISTING TRAFFIC SIGNAL EQUIPMENT SHALL BE REMOVED BY THE CONTRACTOR, AND RELOCATED TO THE PROPOSED MAST ARM ASSEMBLIES AND POLES:

- 2 EACH CONFIRMATION BEACON
- 2 EACH LIGHT DETECTOR

A

LEFT ON
GREEN
ARROW
ONLY

R10-5
30" X 36"
(4 EACH REQUIRED)

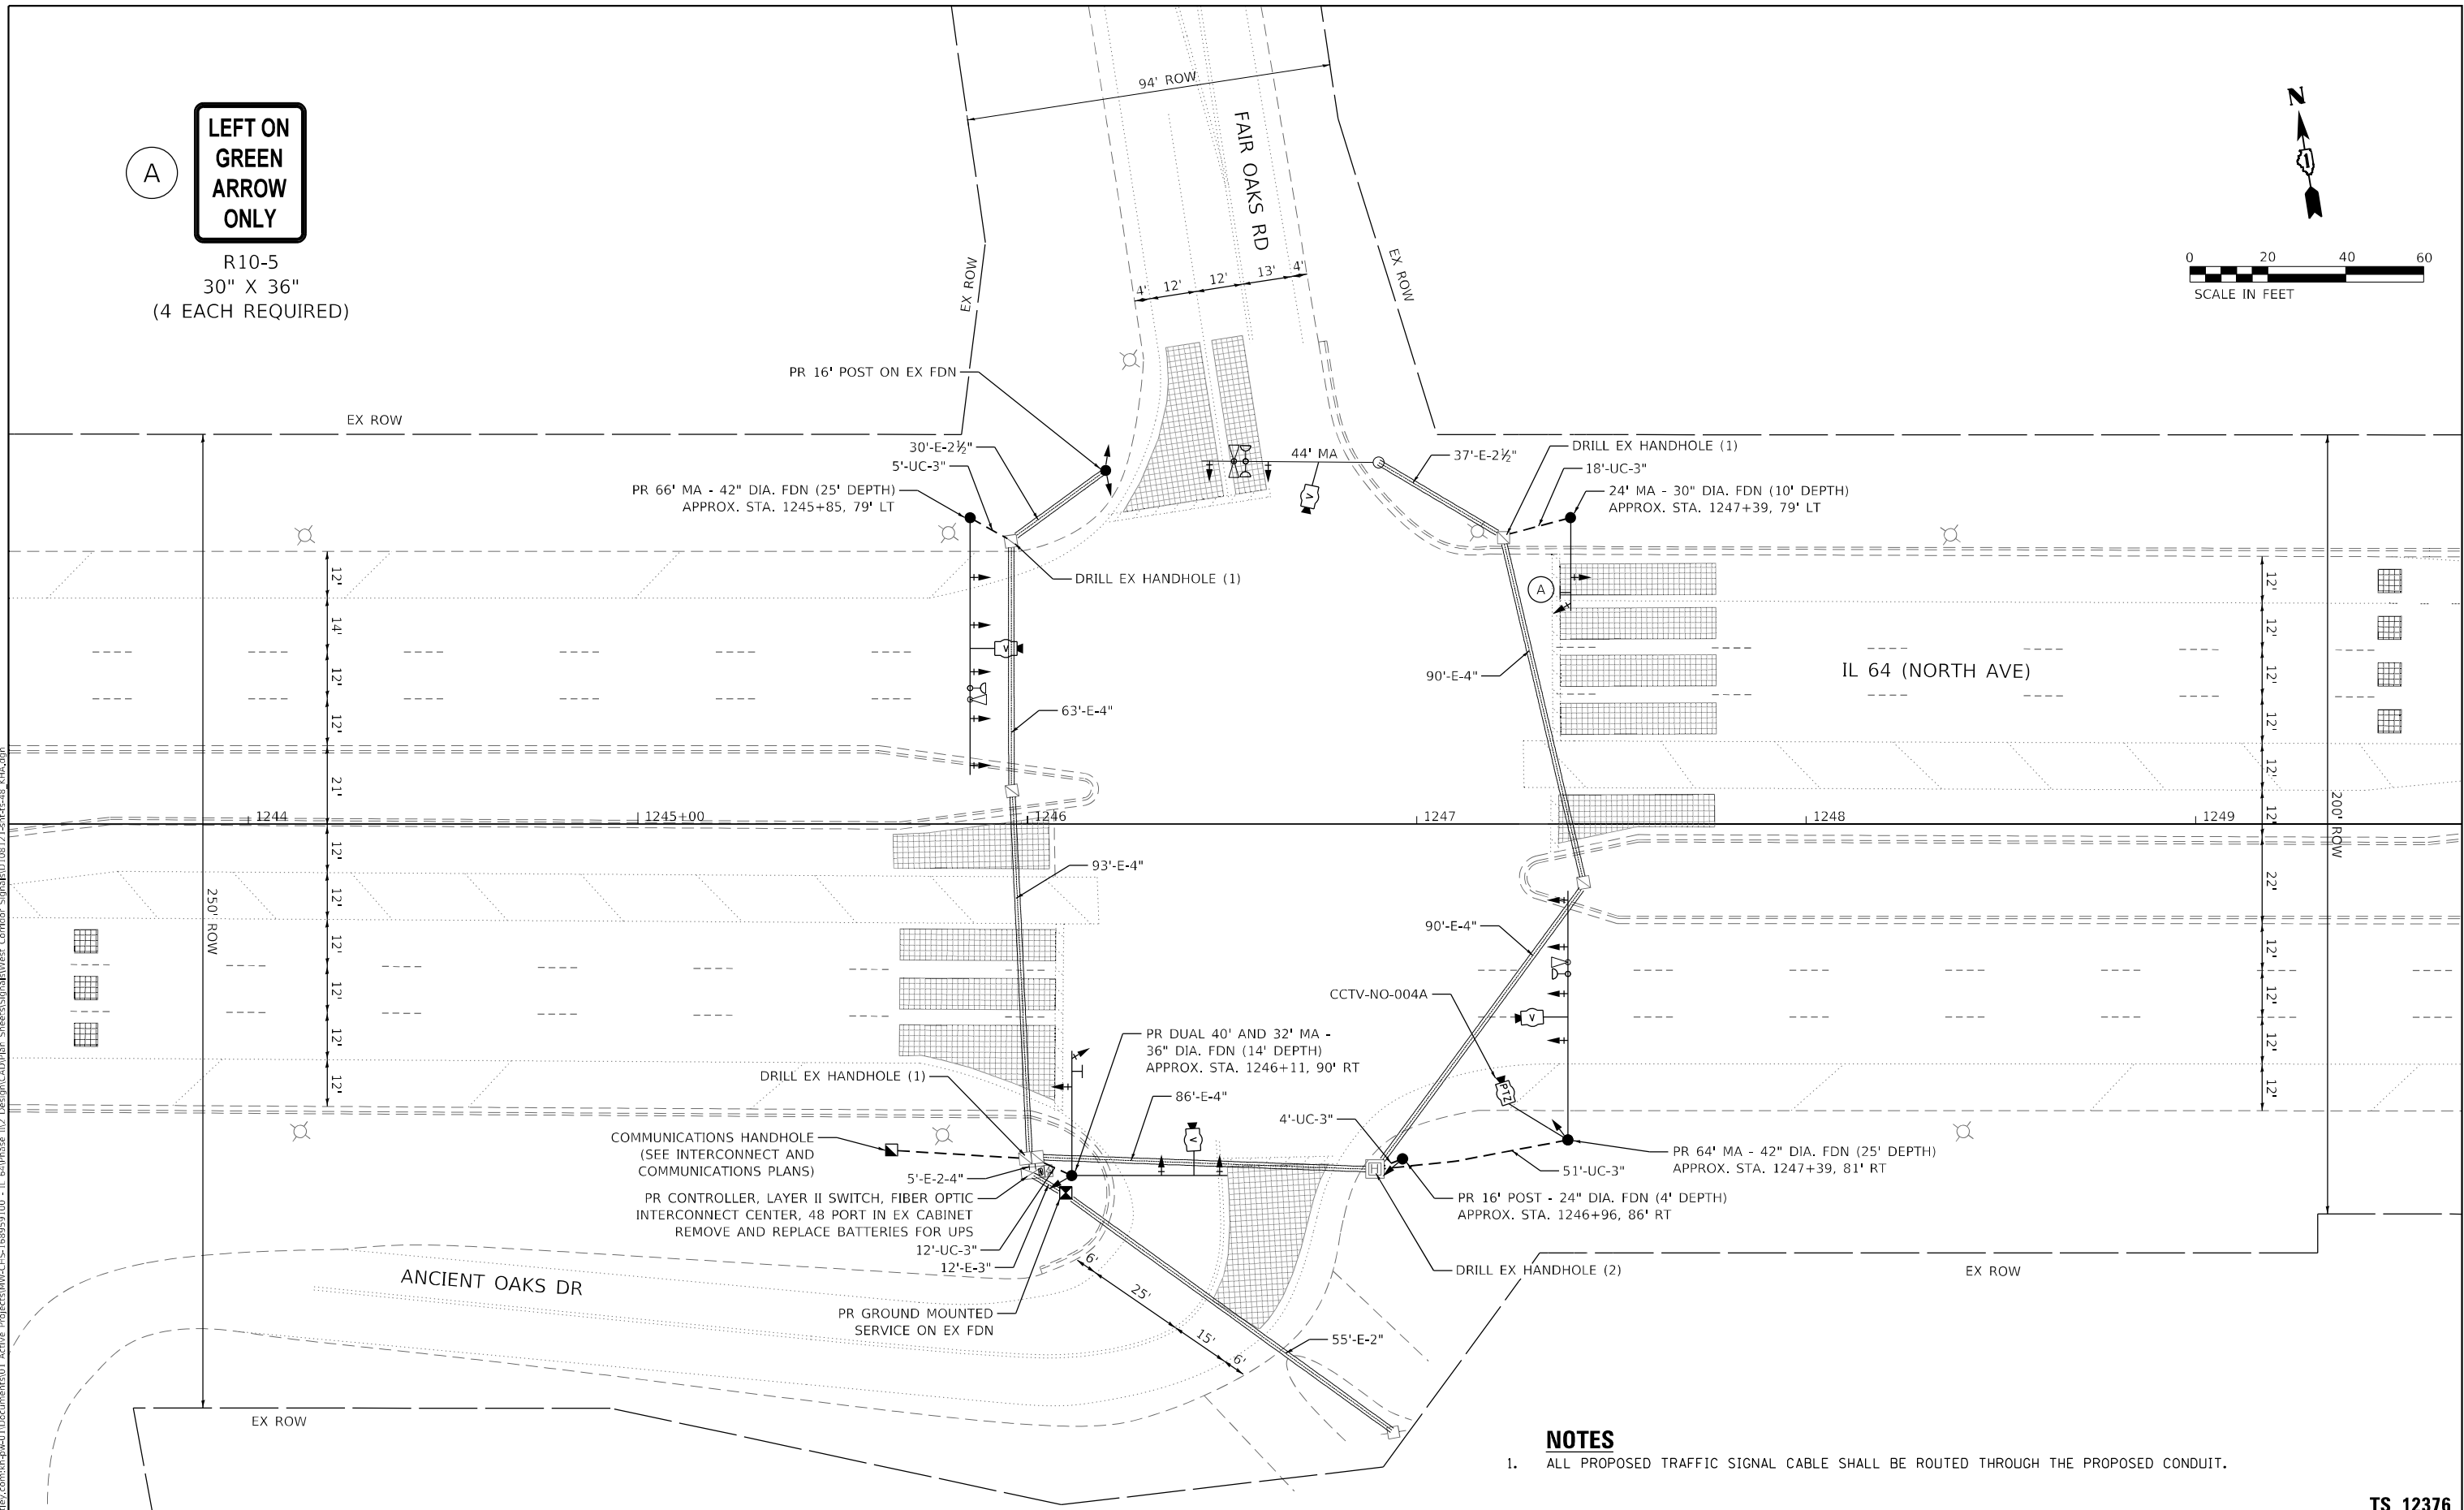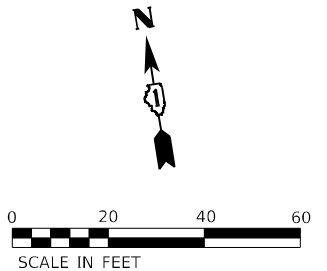

NOTES

1. ALL PROPOSED TRAFFIC SIGNAL CABLE SHALL BE ROUTED THROUGH THE PROPOSED CONDUIT.

TS 12376
IDOT TACTICS
FORMER EAGLE 5A

Kimley»Horn

© 2021 KIMLEY-HORN AND ASSOCIATES, INC.
4001 WILLOW D. ROAD, SUITE 600
WARREN, ILL. 60555
PHONE: (847) 455-4555
WWW.KIMLEY-HORN.COM

USER NAME =	DESIGNED -	REVISED -
	DRAWN -	REVISED -
PLOT SCALE =	CHECKED -	REVISED -
PLOT DATE =	DATE -	REVISED -


STATE OF ILLINOIS
DEPARTMENT OF TRANSPORTATION

TRAFFIC SIGNAL MODERNIZATION PLAN
IL 64 (NORTH AVE) AND FAIR OAKS RD/ANCIENT OAKS DR


SCALE: 1" = 20' SHEET OF SHEETS STA. TO STA.

F.A.P. RTE.	SECTION	COUNTY	TOTAL SHEETS	SHEET NO.
307	2020-263-SUR, SW&TS	DUPAGE	529	149
CONTRACT NO. 62N33				
ILLINOIS FED. AID PROJECT				

 SEQUENCE




SEQUENCE

 

EX INTERCONNECT TO
PRINCE CROSSING RD
(TO BE ABANDONED)

M
.

 VEHICLE PREEMPTION SEQUENCE



LEGEND:

-  PROTECTED PHASE
 PROTECTED/PERMITTED PHASE
 PEDESTRIAN PHASE
 OVERLAP

ELECTRICAL SERVICE REQUIREMENTS

ENERGY COSTS TO:
ILLINOIS DEPARTMENT OF TRANSPORTATION
201 W CENTER CT
SCHAUMBURG, IL 60196

ENERGY SUPPLY: COMPANY: COMED
PHONE: (866) 639-3532
ACCOUNT NUMBER: 28380-06047

(NOT TO SCALE)



TS 12376
IDOT TACTICS
FORMER EAGLE 5A

F.A.P. RTE.	SECTION	COUNTY	TOTAL SHEETS	SHEET NO.
307	2020-263-SUR,SW&TS	DUPAGE	529	150
		CONTRACT NO. 62N33		
ILLINOIS		FED. AID PROJECT		

STATE OF ILLINOIS
DEPARTMENT OF TRANSPORTATION

CABLE PLAN, PHASE DESIGNATION DIAGRAM, AND EMERGENCY VEHICLE PREEMPTION SEQUENCE IL 64 (NORTH AVE) AND FAIR OAKS RD/ANCIENT OAKS DR				
SCALE: N.T.S.	SHEET	OF	SHEETS	STA. TO STA.

© 2023 KIMLEY-HORN AND ASSOCIATES, INC.
4201 WINFIELD ROAD, SUITE 603
WARREN, IL 60555
PHONE: 830-487-6550
WWW.KIMLEY-HORN.COM

MODEL: Default
 PROFILE NAME: nw\lfr-nw\hantley.com\hantley\Documents\01_Active_Projects\MMW\CHS_168950100 - II_64\Phase_III_Desim\Caplan_Sheets\Signal\West_Corridor_Signal\108121-sht-15-49_KHA.dgn

SIGN PANEL – TYPE 2

ALL DIMENSIONS ARE IN INCHES UNLESS OTHERWISE NOTED



DESIGN SERIES	AREA (SQ FT)	SIGN PANEL TYPE	SHEETING TYPE	QTY. REQUIRED
D	12.5	2	ZZ	2



DESIGN SERIES	AREA (SQ FT)	SIGN PANEL TYPE	SHEETING TYPE	QTY. REQUIRED
C	20	2	ZZ	1



DESIGN SERIES	AREA (SQ FT)	SIGN PANEL TYPE	SHEETING TYPE	QTY. REQUIRED
C	20	2	ZZ	1

SCHEDULE OF QUANTITIES

ITEM DESCRIPTION	UNIT	QUANTITY
SIGN PANEL - TYPE 2	SQ FT	105
UNDERGROUND CONDUIT, GALVANIZED STEEL, 2" DIA.	FOOT	5
UNDERGROUND CONDUIT, GALVANIZED STEEL, 3" DIA.	FOOT	90
MAINTENANCE OF EXISTING TRAFFIC SIGNAL INSTALLATION	EACH	1
ELECTRIC CABLE IN CONDUIT, SIGNAL NO. 14 3C	FOOT	551
ELECTRIC CABLE IN CONDUIT, SIGNAL NO. 14 5C	FOOT	3596
ELECTRIC CABLE IN CONDUIT, SIGNAL NO. 14 7C	FOOT	1026
ELECTRIC CABLE IN CONDUIT, SERVICE, NO. 6 2 C	FOOT	549
ELECTRIC CABLE IN CONDUIT, EQUIPMENT GROUNDING CONDUCTOR, NO. 6 1C	FOOT	114
TRAFFIC SIGNAL POST, GALVANIZED STEEL 16 FT.	EACH	2
STEEL MAST ARM ASSEMBLY AND POLE, 24 FT.	EACH	1
STEEL MAST ARM ASSEMBLY AND POLE, 64 FT.	EACH	1
STEEL MAST ARM ASSEMBLY AND POLE, 66 FT.	EACH	1
STEEL MAST ARM ASSEMBLY AND POLE WITH DUAL MAST ARMS, 32 FT. AND 40 FT.	EACH	1
CONCRETE FOUNDATION, TYPE A	FOOT	8
CONCRETE FOUNDATION, TYPE E 30-INCH DIAMETER	FOOT	10
CONCRETE FOUNDATION, TYPE E 36-INCH DIAMETER	FOOT	14
CONCRETE FOUNDATION, TYPE E 42-INCH DIAMETER	FOOT	50
DRILL EXISTING HANDHOLE	EACH	5
SIGNAL HEAD, LED, 1-FACE, 3-SECTION, MAST-ARM MOUNTED	EACH	14
SIGNAL HEAD, LED, 1-FACE, 3-SECTION, BRACKET MOUNTED	EACH	4
SIGNAL HEAD, LED, 1-FACE, 5-SECTION, BRACKET MOUNTED	EACH	1
SIGNAL HEAD, LED, 1-FACE, 5-SECTION, MAST-ARM MOUNTED	EACH	3
TRAFFIC SIGNAL BACKPLATE, LOUVERED, FORMED PLASTIC	EACH	17
* RELOCATE EXISTING EMERGENCY VEHICLE PRIORITY SYSTEM, DETECTOR UNIT	EACH	2
REMOVE ELECTRIC CABLE FROM CONDUIT	FOOT	2
REMOVE EXISTING TRAFFIC SIGNAL EQUIPMENT	EACH	1
REMOVE EXISTING CONCRETE FOUNDATION	EACH	5
CLOSED CIRCUIT TELEVISION DOME CAMERA, HD	EACH	1
* EMERGENCY VEHICLE PRIORITY SYSTEM LINE SENSOR CABLE, NO. 20 3/C	FOOT	549
OUTDOOR RATED NETWORK CABLE	FOOT	258
SERVICE INSTALLATION, GROUND MOUNTED, METERED	EACH	1
REMOTE CONTROLLED VIDEO SYSTEM	EACH	1
LAYER II (DATALINK) SWITCH	EACH	1
TERMINATE FIBER IN CABINET	EACH	12
TACTICS LICENSE EXPANSION	EACH	1
FULL-ACTUATED CONTROLLER IN EXISTING CABINET	EACH	1
REMOVE AND REPLACE BATTERIES FOR UNINTERRUPTABLE POWER SUPPLY, EXTENDED	EACH	1
FIBER OPTIC INTERCONNECT CENTER, 48 PORT	EACH	1
LED SIGNAL FACE, LENS COVER	EACH	22
VIDEO VEHICLE DETECTION SYSTEM, SINGLE APPROACH	EACH	4
CAMERA MOUNTING ASSEMBLY	EACH	1

* - 100% COST TO WAYNE TOWNSHIP

TS 12376
IDOT TACTICS
FORMER EAGLE 5A

MODEL: Default
FILE: I:\MISC\proj\sub-pw\bartley.com\ktp\p4-d1\documents\01 Active Projects\MMW-CHS-168950\100 - IL 64\Phase II\2 Design\CAD\Plan_Sheets\Sign\Wet_Corridor_Signals\ID1081714-IL-Rte-50_KVA.dgn

KimleyHorn

© 2023 KIMLEY-HORN AND ASSOCIATES, INC.
4001 HWY 10, SUITE 600
WARREN, IL 60555
PHONE: 815.447.4555
WWW.KIMLEY-HORN.COM

USER NAME =

DESIGNED -

REVISED -

DRAWN -

REVIS

REVISED -

PLOT SCALE =

CHECKED -

REVISED -

PLOT DATE =

DATE -

REVISED -

STATE OF ILLINOIS
DEPARTMENT OF TRANSPORTATION

SCHEDULE OF QUANTITIES
IL 64 (NORTH AVE) AND FAIR OAKS RD/ANCIENT OAKS DR

SCALE: N.T.S.

SHEET

OF

SHEETS

STA.

TO STA.

F.A.P.
RTE.

SECTION

COUNTY

TOTAL
SHEETS

SHEET
NO.

307

2020-263-SUR,SW&TS

DUPAGE

529


151

CONTRACT NO. 62N33

ILLINOIS FED. AID PROJECT

NOTES

1. THE EXISTING TRAFFIC SIGNAL EQUIPMENT SHALL NOT BE REMOVED UNTIL THE PROPOSED TRAFFIC SIGNAL EQUIPMENT IS FULLY OPERATIONAL OR AS DIRECTED BY THE ENGINEER.
2. ALL EXISTING TRAFFIC SIGNAL CABLE NO LONGER REQUIRED SHALL BE REMOVED.

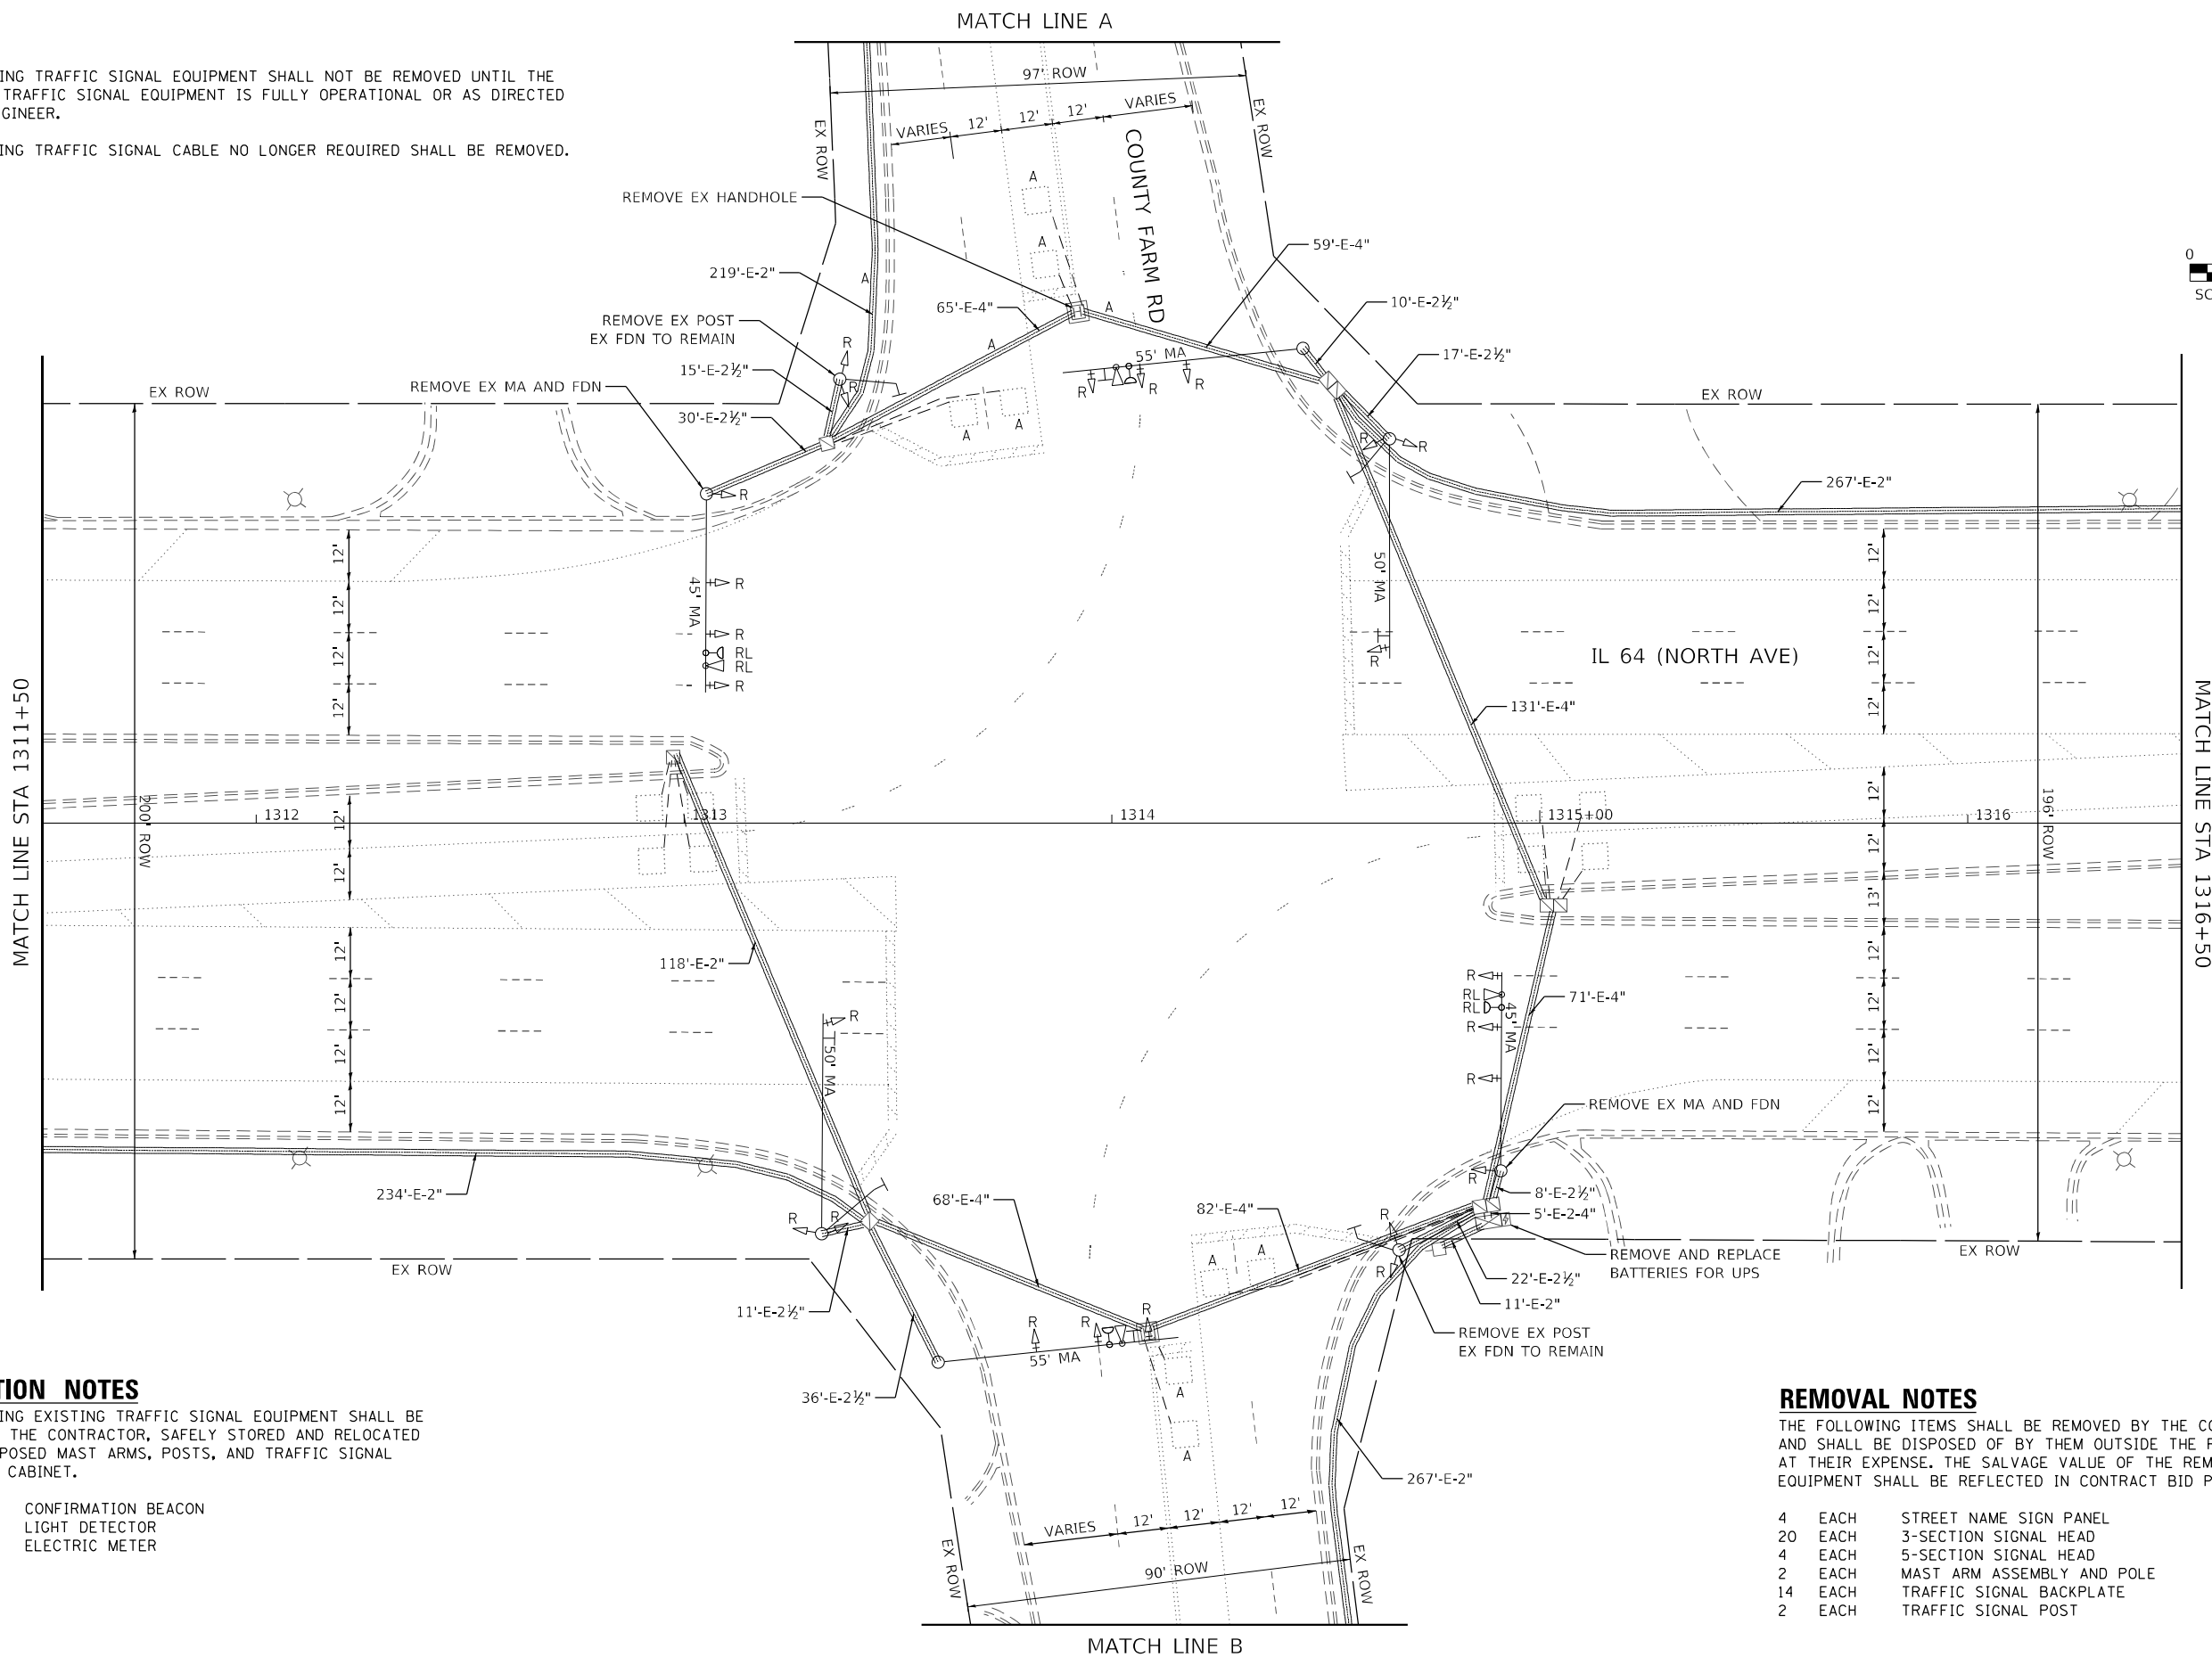

RELOCATION NOTES

THE FOLLOWING EXISTING TRAFFIC SIGNAL EQUIPMENT SHALL BE REMOVED BY THE CONTRACTOR, SAFELY STORED AND RELOCATED TO THE PROPOSED MAST ARMS, POSTS, AND TRAFFIC SIGNAL CONTROLLER CABINET.

- | | | |
|---|------|---------------------|
| 2 | EACH | CONFIRMATION BEACON |
| 2 | EACH | LIGHT DETECTOR |
| 1 | EACH | ELECTRIC METER |

REMOVAL NOTES

THE FOLLOWING ITEMS SHALL BE REMOVED BY THE CONTRACTOR AND SHALL BE DISPOSED OF BY THEM OUTSIDE THE RIGHT-OF-WAY AT THEIR EXPENSE. THE SALVAGE VALUE OF THE REMOVED EQUIPMENT SHALL BE REFLECTED IN CONTRACT BID PRICE.

- | | | |
|----|------|----------------------------|
| 4 | EACH | STREET NAME SIGN PANEL |
| 20 | EACH | 3-SECTION SIGNAL HEAD |
| 4 | EACH | 5-SECTION SIGNAL HEAD |
| 2 | EACH | MAST ARM ASSEMBLY AND POLE |
| 14 | EACH | TRAFFIC SIGNAL BACKPLATE |
| 2 | EACH | TRAFFIC SIGNAL POST |

MODEL: Default
FILE: \\naulic-prod\hwy-bentley\com\hwy-bentley\documents\01 Active Projects\IWK-CHS-168950\100 - IL 64\Phase II\2 Design\CAD\Plan_Sheets\Signal\West Corridor_Signal\108171-14-14-ts-51_K4A.dgn



© 2023 KIMLEY-HORN AND ASSOCIATES, INC.
4001 WILMINGTON ROAD, SUITE 600
WARREN, ILL. 60555
PHONE: 815.447.4555
WWW.KIMLEY-HORN.COM

USER NAME	=	DESIGNED	-	REVISED	-
		DRAWN	-	REVISED	-
PLOT SCALE	=	CHECKED	-	REVISED	-
PLOT DATE	=	DATE	-	REVISED	-

STATE OF ILLINOIS
DEPARTMENT OF TRANSPORTATION

TRAFFIC SIGNAL EQUIPMENT REMOVAL PLAN
IL 64 (NORTH AVE) AND COUNTY FARM RD



SCALE: 1" = 20' SHEET OF SHEETS STA. TO STA.

F.A.P. RTE.	SECTION	COUNTY	TOTAL SHEETS	SHEET NO.
307	2020-263-SUR, SW&TS	DUPAGE	529	152
CONTRACT NO. 62N33				
ILLINOIS FED. AID PROJECT				

TS 6425
IDOT TACTICS
FORMER EAGLE 2E

NOTES

1. ALL PROPOSED TRAFFIC SIGNAL CABLE SHALL BE ROUTED THROUGH THE PROPOSED CONDUIT.
2. A SEPARATE LEAD-IN CABLE SHALL BE INSTALLED FOR THE DETECTOR LOOPS ON IL 64 (NORTH AVE).
3. THE EXISTING SERVICE METER SHALL BE RELOCATED TO THE PROPOSED GROUND MOUNTED SERVICE CABINET. THE EXISTING SERVICE METER HOUSING SHALL REMAIN AT THE EXISTING TRAFFIC SIGNAL CONTROLLER CABINET AND ALL HOLES BETWEEN THE EXISTING HOUSING AND THE EXISTING CABINET SHALL BE PLUGGED. THIS WORK SHALL BE INCLUDED IN THE PAY ITEM SERVICE INSTALLATION, GROUND MOUNTED, METERED.
4. PROPOSED CONDUIT SHALL BE SPLICED TO THE EXISTING CONDUIT AND EXTENDED VERTICALLY THROUGH THE PROPOSED FOUNDATION AT THE GROUND MOUNTED SERVICE LOCATION. THE COST OF THE CONDUIT SHALL BE INCLUDED IN THE COST OF CONCRETE FOUNDATION, TYPE A.

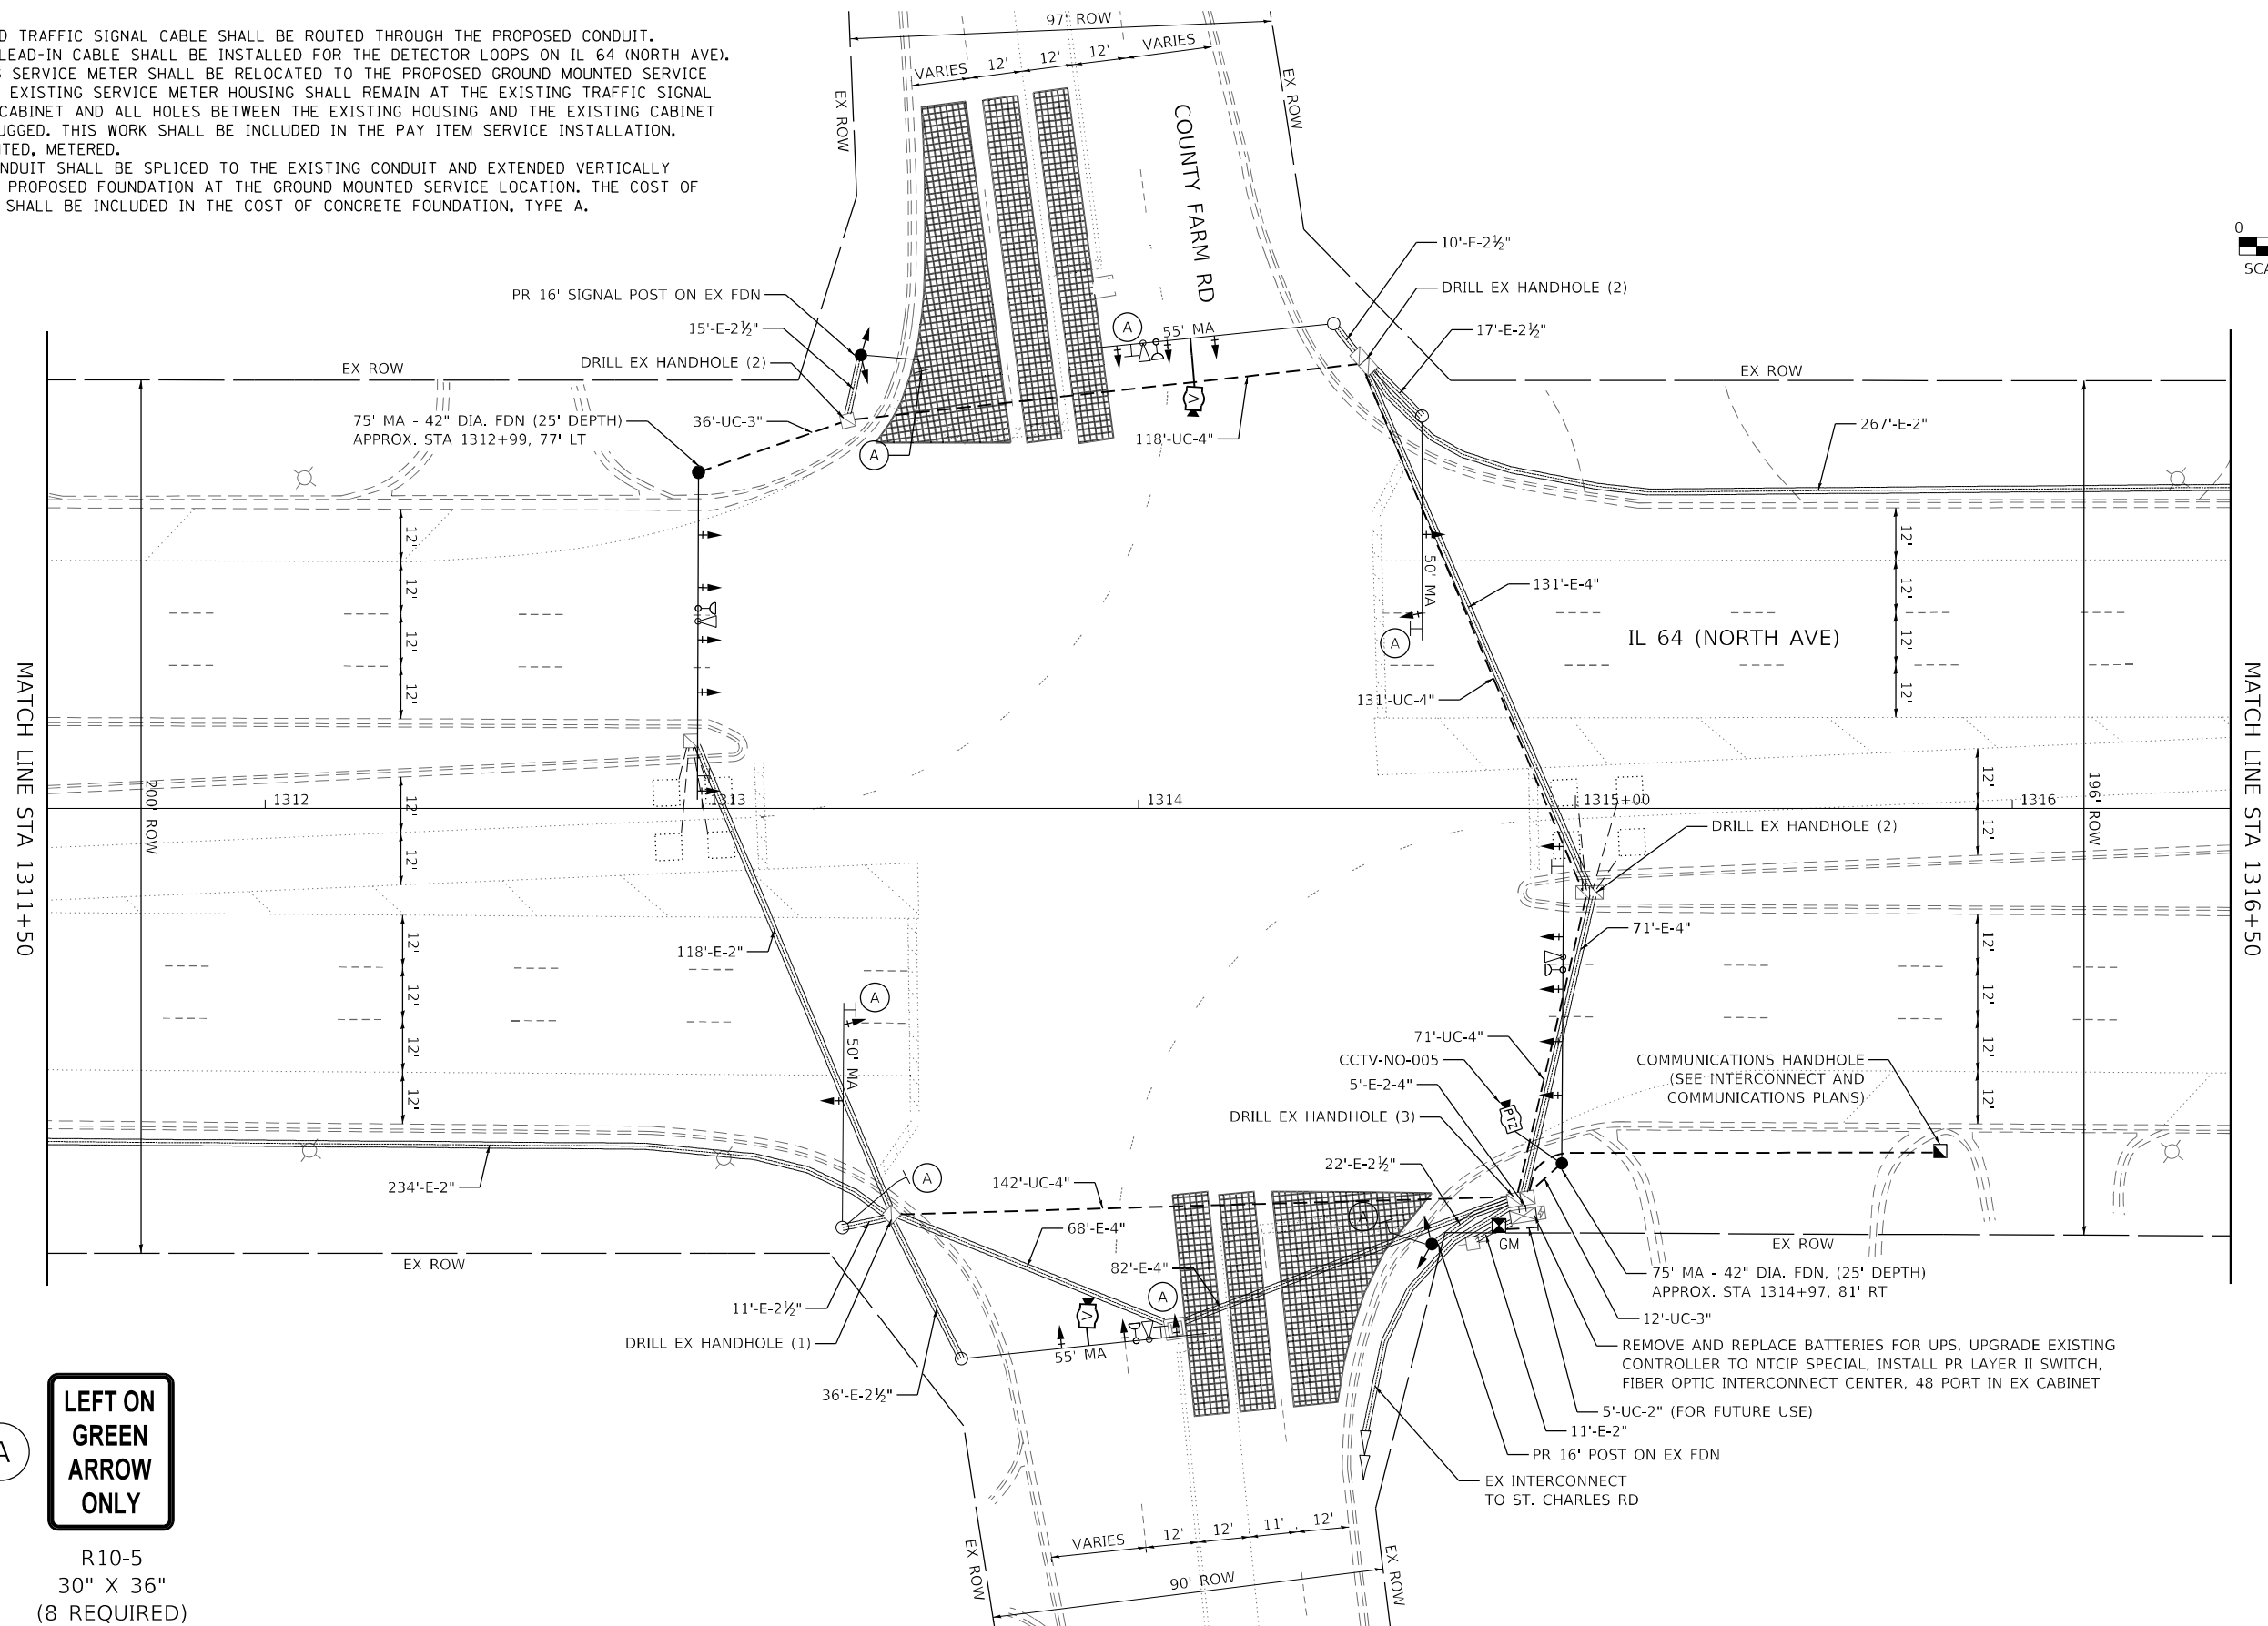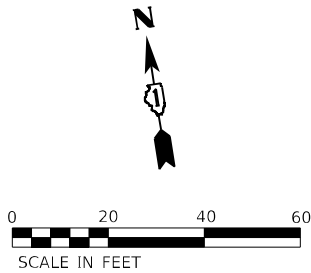

LEFT ON
GREEN
ARROW
ONLY

R10-5
30" X 36"
(8 REQUIRED)

MODEL: Default
FILE NAME: p:\work\how.bartley\comshp\p01\Documents\01 Active Projects\MM\CHS-168950\100 - IL 64\Phase 1\2 Design\CAD\Plan Sheets\Signal\West Corridor Signal\01081214\ts-53_K4A.dgn

KimleyHorn
© 2023 KIMLEY-HORN AND ASSOCIATES, INC.
4001 WINDFIELD ROAD, SUITE 600
WARRENVILLE, IL 60555
PHONE: 630.474.4550
WWW.KIMLEY-HORN.COM

USER NAME =	DESIGNED -	REVISED -
	DRAWN -	REVISED -
PLOT SCALE =	CHECKED -	REVISED -
PLOT DATE =	DATE -	REVISED -

STATE OF ILLINOIS
DEPARTMENT OF TRANSPORTATION

TRAFFIC SIGNAL MODERNIZATION PLAN
IL 64 (NORTH AVE) AND COUNTY FARM RD

SCALE: 1" = 20' SHEET OF SHEETS STA. TO STA.

F.A.P. RTE.	SECTION	COUNTY	TOTAL SHEETS	SHEET NO.
307	2020-263-SUR, SW&TS	DUPAGE	529	154
CONTRACT NO. 62N33				
ILLINOIS FED. AID PROJECT				

TS 6425
IDOT TACTICS
FORMER EAGLE 2E

MODEL: Default
FILE NAME: p:\sub-pw\bartley.com\k-h-pw-d\Documents\01 Active Projects\MW\CHS-168950\00 - IL 64\Phase 1\2 Design\CAD\Plan Streets\Signal\West Corridor_Signal\01081714-IL-64-K4A.dgn



© 2023 KIMLEY-HORN AND ASSOCIATES, INC.
4001 WHITE OAK ROAD, SUITE 600
WARREN, ILL. 60555
PHONE: 815.447.4555
WWW.KIMLEY-HORN.COM



USER NAME	=	DESIGNED	-
		DRAWN	-
PLOT SCALE	=	CHECKED	-
PLOT DATE	=	DATE	-
		REVISED	-
		REVISED	-
		REVISED	-
		REVISED	-

STATE OF ILLINOIS
DEPARTMENT OF TRANSPORTATION


TRAFFIC SIGNAL MODERNIZATION PLAN			
IL 64 (NORTH AVE) AND COUNTY FARM RD			
SCALE: 1" = 20'	SHEET	OF	SHEETS
	STA.	TO	STA.

F.A.P. RTE.	SECTION	COUNTY	TOTAL SHEETS	SHEET NO.
307	2020-263-SUR,SW&TS	DUPAGE	529	155
CONTRACT NO. 62N33				
		ILLINOIS	FED. AID PROJECT	


TS 6425
IDOT TACTICS
FORMER EAGLE 2E

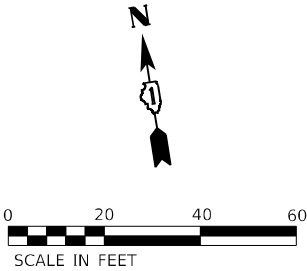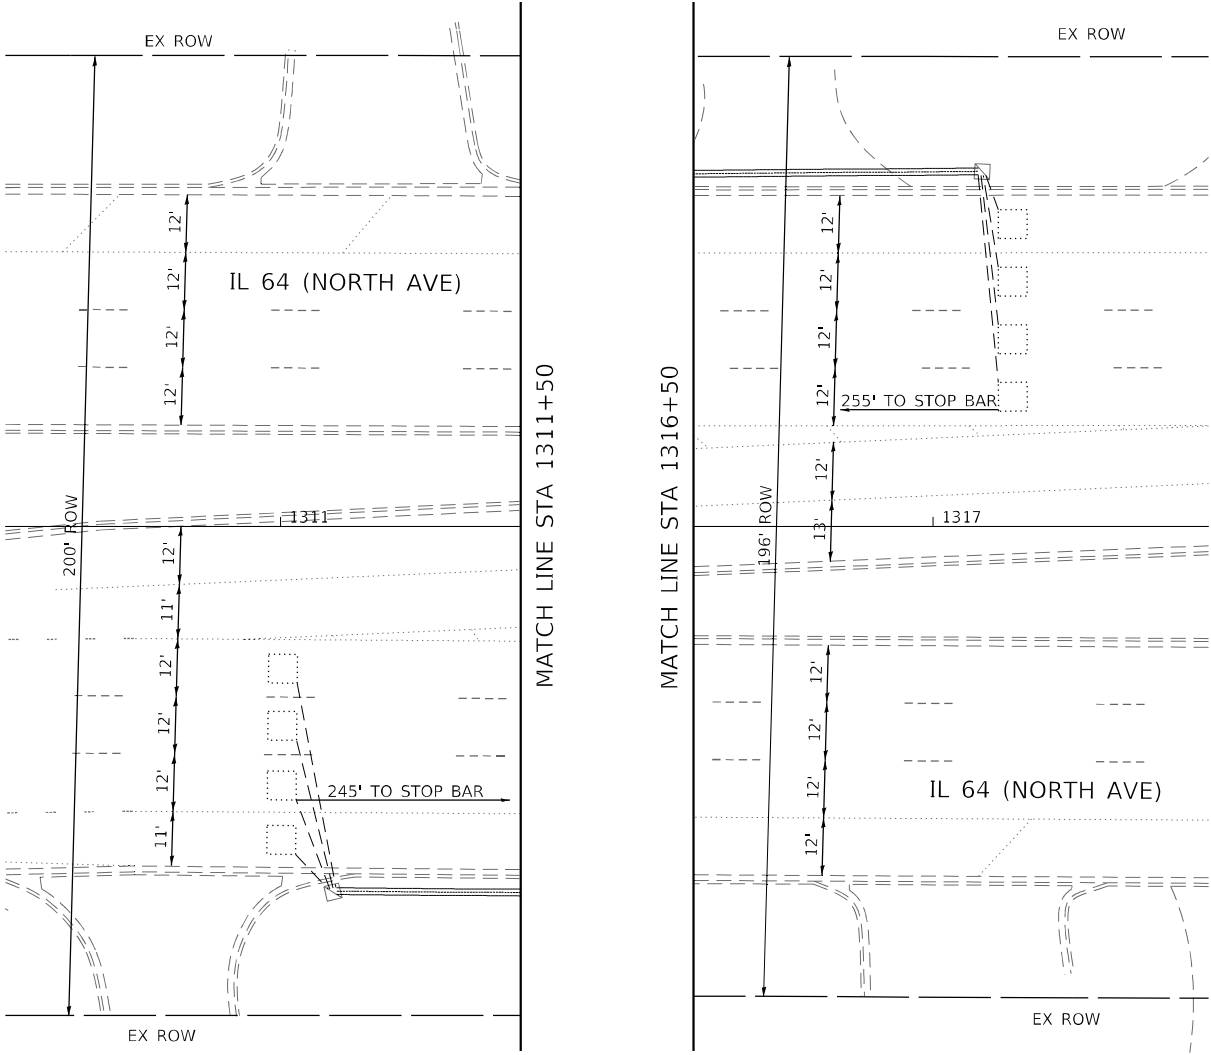

EXISTING AND PROPOSED
CONTROLLER SEQUENCE

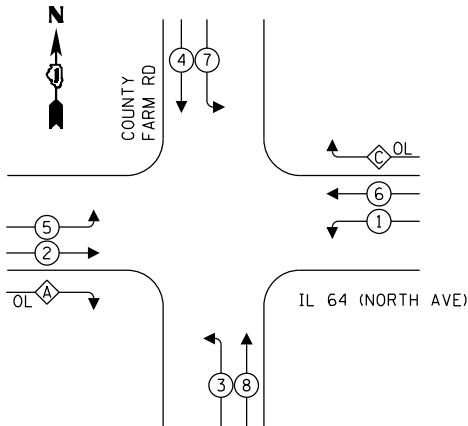


LEGEND:

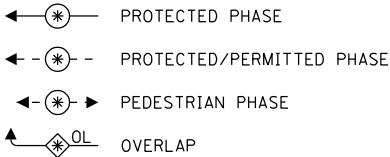

OVERLAP LETTER		PERMISSIVE PHASE		PROTECTED PHASE
A	=	2	+	3
C	=	6	+	7

EXISTING AND PROPOSED EMERGENCY
VEHICLE PREEMPTION SEQUENCE

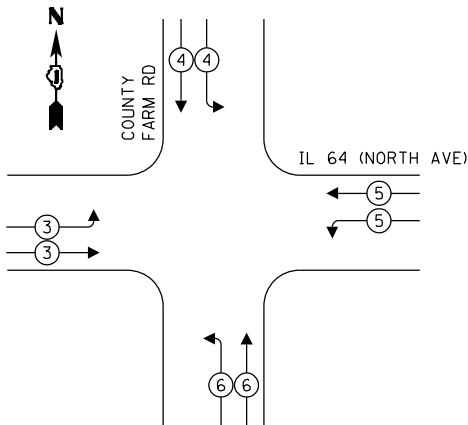


TRAFFIC SIGNAL
ELECTRICAL SERVICE REQUIREMENTS

TYPE	QUANTITY	UNIT WATTAGE	TOTAL WATTAGE
SIGNAL HEAD 1 OR 3-SECTION	20	11	220
4-SECTION	-	14	-
5-SECTION	4	13	52
PROGRAMMABLE 3-SECTION	-	22	-
4-SECTION	-	32	-
5-SECTION	-	28	-
PEDESTRIAN SIGNAL	-	15	-
CONTROLLER	1	150	150
MASTER CONTROLLER	-	100	-
UPS	1	25	25
DETECTION VIDEO	2	20	40
BLANK-OUT SIGN	-	25	-
NETWORK SWITCH LAYER II OR III	1	35	35
CELLULAR MODEM	-	15	-
PTZ	1	75	75
TOTAL UPS SIZING		597	
UPS CHARGING	1	225	225
BATTERY HEATER MAT	1	180	180
CABINET HEATER	1	200	200
FLASHER	-	15	-
LED STREET NAME SIGN	-	120	-
LUMINAIRE	-	240	-
TOTAL SERVICE WIRE SIZING		1202	

ENERGY COSTS TO:
ILLINOIS DEPARTMENT OF TRANSPORTATION
201 W CENTER CT
SCHAUMBURG, IL 60196

ENERGY SUPPLY: COMPANY: COMED
PHONE: (866) 639-3532
ACCOUNT NUMBER: 28380-06047

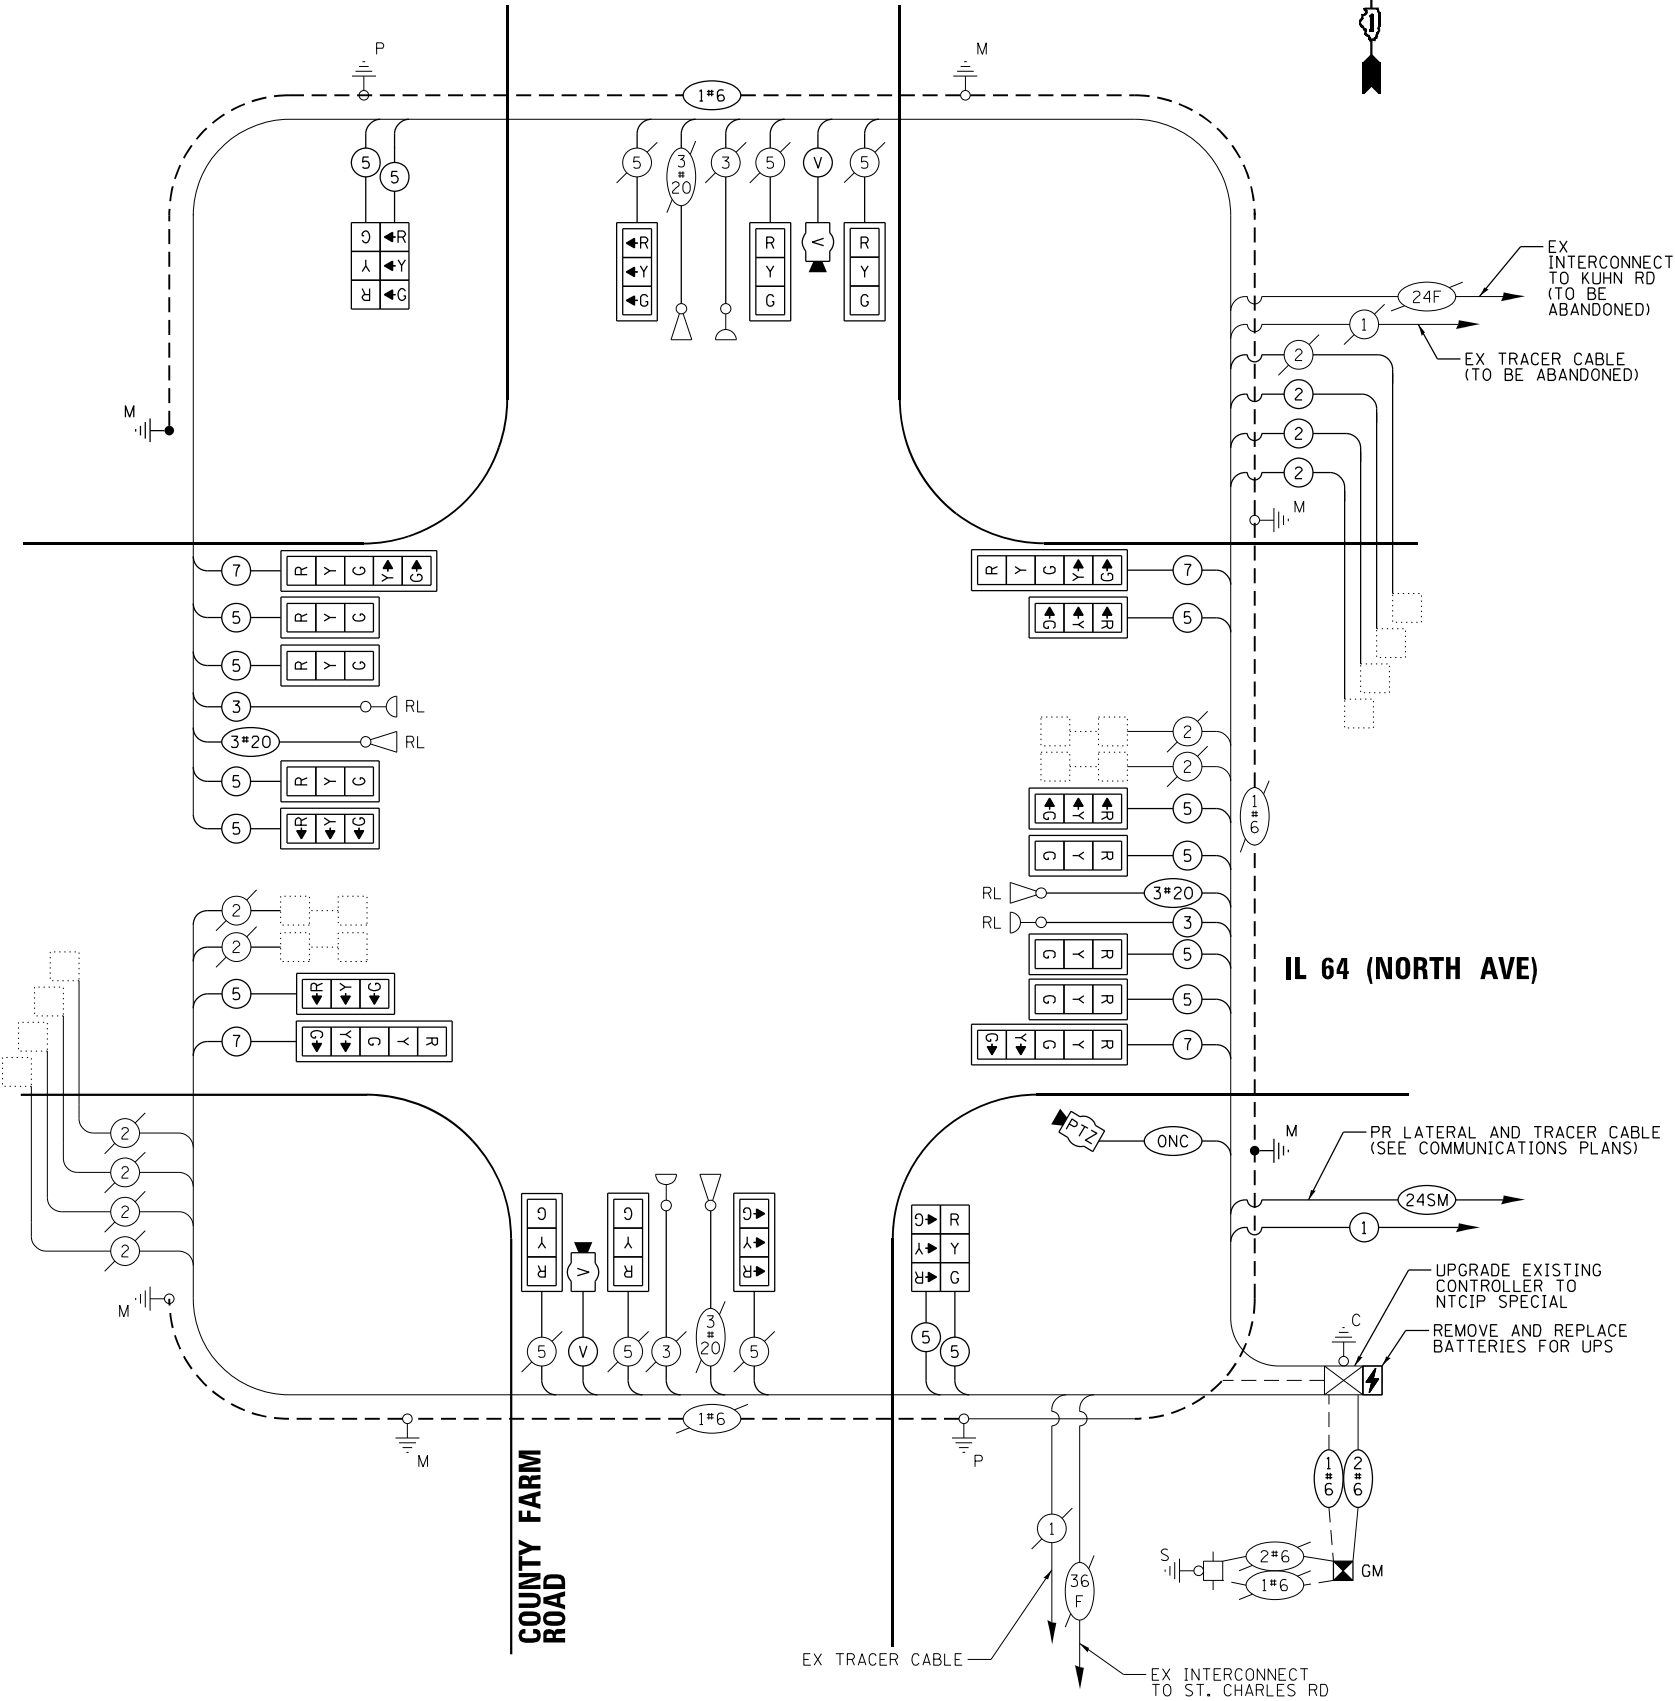

CABLE PLAN
(NOT TO SCALE)

TS 6425
IDOT TACTICS
FORMER EAGLE 2E

KimleyHorn

© 2023 KIMLEY-HORN AND ASSOCIATES, INC.
4001 WILLOW D. ROAD, SUITE 600
WARREN, IL 6. 0585
PHONE: (847) 455-4555
WWW.KIMLEY-HORN.COM

USER NAME	=	
PLOT SCALE	=	
PLOT DATE	=	

DESIGNED	-	REVISED	-
DRAWN	-	REVISED	-
CHECKED	-	REVISED	-
DATE	-	REVISED	-



STATE OF ILLINOIS
DEPARTMENT OF TRANSPORTATION

CABLE PLAN, PHASE DESIGNATION DIAGRAM, AND
EMERGENCY VEHICLE PREEMPTION SEQUENCE
IL 64 (NORTH AVE) AND COUNTY FARM RD

SCALE: N.T.S. SHEET OF SHEETS STA. TO STA.

F.A.P. RTE.	SECTION	COUNTY	TOTAL SHEETS	SHEET NO.
307	2020-263-SUR, SW&TS	DUPAGE	529	156
CONTRACT NO. 62N33				
ILLINOIS FED. AID PROJECT				

  
ALL DIMENSIONS ARE IN INCHES UNLESS OTHERWISE NOTED



ITEM DESCRIPTION	UNIT	QUANTITY
SIGN PANEL - TYPE 2	SQ FT	47.5
UNDERGROUND CONDUIT, GALVANIZED STEEL, 2" DIA.	FOOT	5
UNDERGROUND CONDUIT, GALVANIZED STEEL, 3" DIA.	FOOT	48
UNDERGROUND CONDUIT, GALVANIZED STEEL, 4" DIA.	FOOT	462
MAINTENANCE OF EXISTING TRAFFIC SIGNAL INSTALLATION	EACH	1
ELECTRIC CABLE IN CONDUIT, SIGNAL NO. 14 3C	FOOT	652
ELECTRIC CABLE IN CONDUIT, SIGNAL NO. 14 5C	FOOT	4168
ELECTRIC CABLE IN CONDUIT, SIGNAL NO. 14 7C	FOOT	1258
ELECTRIC CABLE IN CONDUIT, LEAD-IN, NO. 14 1 PAIR	FOOT	1422
ELECTRIC CABLE IN CONDUIT, SERVICE, NO. 6 2 C	FOOT	36
ELECTRIC CABLE IN CONDUIT, EQUIPMENT GROUNDING CONDUCTOR, NO. 6 1C	FOOT	546
TRAFFIC SIGNAL POST, GALVANIZED STEEL 16 FT.	EACH	2
STEEL MAST ARM ASSEMBLY AND POLE, 75 FT.	EACH	2
CONCRETE FOUNDATION, TYPE A	FOOT	4
CONCRETE FOUNDATION, TYPE E 42-INCH DIAMETER	FOOT	50
DRILL EXISTING HANDHOLE	EACH	10
SIGNAL HEAD, LED, 1-FACE, 3-SECTION, MAST-ARM MOUNTED	EACH	16
SIGNAL HEAD, LED, 1-FACE, 3-SECTION, BRACKET MOUNTED	EACH	4
SIGNAL HEAD, LED, 1-FACE, 5-SECTION, MAST-ARM MOUNTED	EACH	4
TRAFFIC SIGNAL BACKPLATE, LOUVERED, FORMED PLASTIC	EACH	20
RELOCATE EXISTING EMERGENCY VEHICLE PRIORITY SYSTEM, DETECTOR UNIT	EACH	2
REMOVE ELECTRIC CABLE FROM CONDUIT	FOOT	8082
REMOVE EXISTING TRAFFIC SIGNAL EQUIPMENT	EACH	1
REMOVE EXISTING HANDHOLE	EACH	1
REMOVE EXISTING CONCRETE FOUNDATION	EACH	2
CLOSED CIRCUIT TELEVISION DOME CAMERA, HD	EACH	1
EMERGENCY VEHICLE PRIORITY SYSTEM LINE SENSOR CABLE, NO. 20 3/C	FOOT	652
OUTDOOR RATED NETWORK CABLE	FOOT	138
SERVICE INSTALLATION, GROUND MOUNTED, METERED	EACH	1
REMOTE CONTROLLED VIDEO SYSTEM	EACH	1
LAYER II (DATALINK) SWITCH	EACH	1
TERMINATE FIBER IN CABINET	EACH	24
UPGRADE EXISTING CONTROLLER TO NTCIP SPECIAL	EACH	1
TACTICS LICENSE EXPANSION	EACH	1
REMOVE AND REPLACE BATTERIES FOR UNINTERUPTABLE POWER SUPPLY, EXTENDED	EACH	1
FIBER OPTIC INTERCONNECT CENTER, 48 PORT	EACH	1
LED SIGNAL FACE, LENS COVER	EACH	24
VIDEO VEHICLE DETECTION SYSTEM, SINGLE APPROACH	EACH	2

**TS 6425
IDOT TACTICS
FORMER EAGLE 2E**

1. THE EXISTING TRAFFIC SIGNAL EQUIPMENT SHALL NOT BE REMOVED UNTIL THE PROPOSED TRAFFIC SIGNAL EQUIPMENT IS FULLY OPERATIONAL OR AS DIRECTED BY THE ENGINEER.
2. ALL EXISTING TRAFFIC SIGNAL CABLE NO LONGER REQUIRED SHALL BE REMOVED.


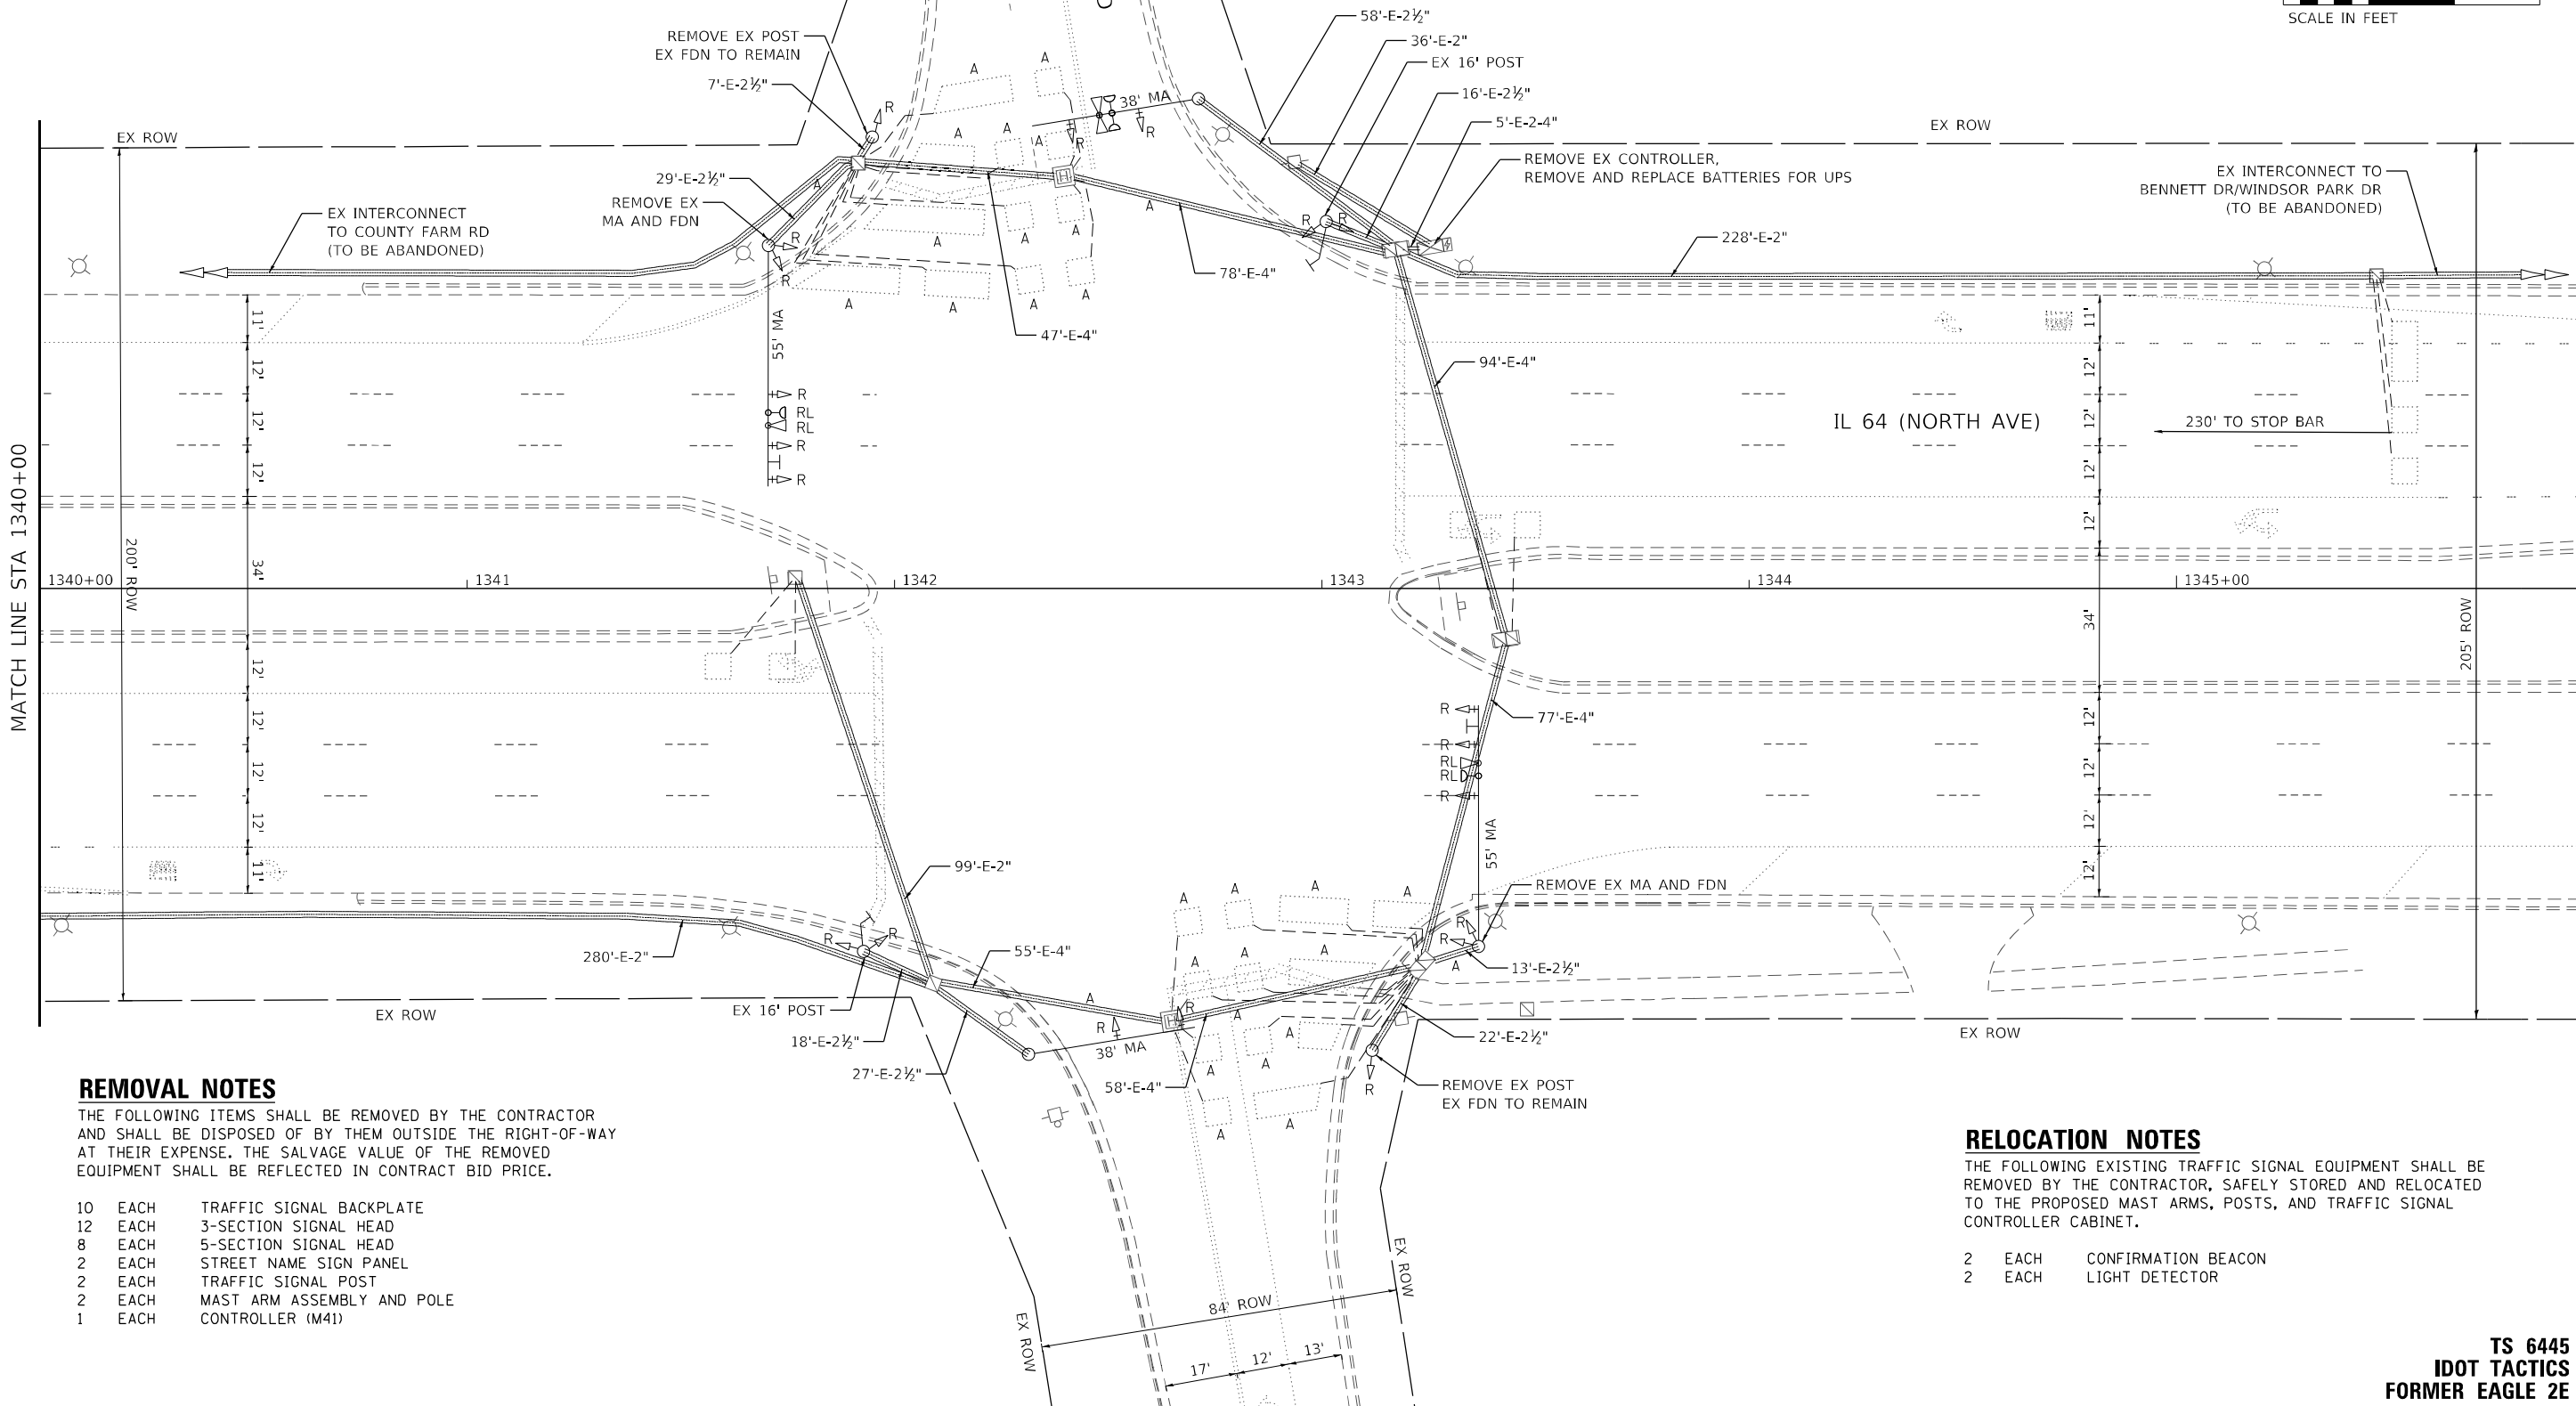


THE FOLLOWING ITEMS SHALL BE REMOVED BY THE CONTRACTOR AND SHALL BE DISPOSED OF BY THEM OUTSIDE THE RIGHT-OF-WAY AT THEIR EXPENSE. THE SALVAGE VALUE OF THE REMOVED EQUIPMENT SHALL BE REFLECTED IN CONTRACT BID PRICE.

10	EACH	TRAFFIC SIGNAL BACKPLATE
12	EACH	3-SECTION SIGNAL HEAD
8	EACH	5-SECTION SIGNAL HEAD
2	EACH	STREET NAME SIGN PANEL
2	EACH	TRAFFIC SIGNAL POST
2	EACH	MAST ARM ASSEMBLY AND POLE
1	EACH	CONTROLLER (M41)

THE FOLLOWING EXISTING TRAFFIC SIGNAL EQUIPMENT SHALL BE REMOVED BY THE CONTRACTOR, SAFELY STORED AND RELOCATED TO THE PROPOSED MAST ARMS, POSTS, AND TRAFFIC SIGNAL CONTROLLER CABINET.

2 EACH CONFIRMATION BEACON
2 EACH LIGHT DETECTOR

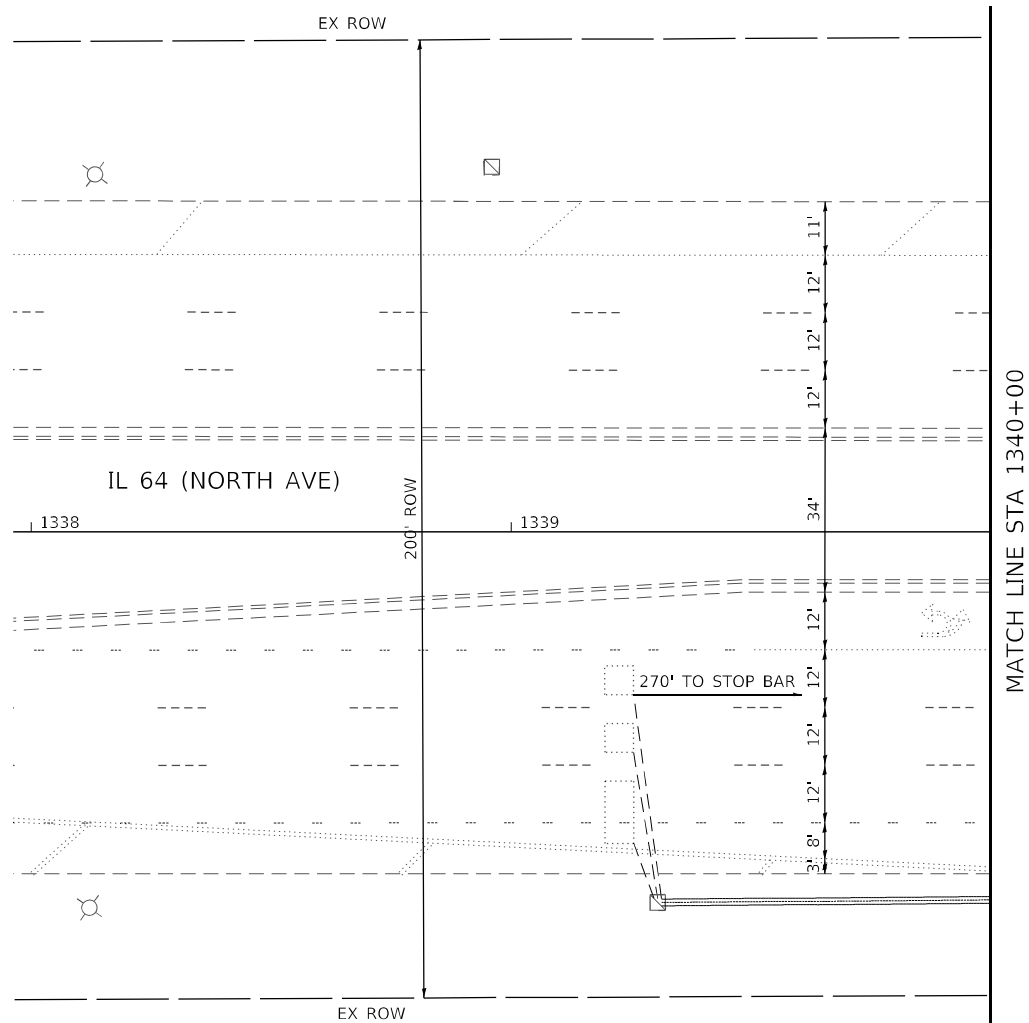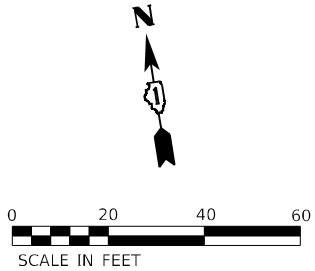

MODEL: Default
FILE NAME: p:\sub-pw\bartley.com\k-h-pw-d1\Documents\01 Active Projects\MW\CL-S-160950\00 - IL 64\Phase 1\2 Design\CAD\Plan Sheets\Signal\West Corridor_Signal\010817-14-14-58_K44.dgn



USER NAME =	DESIGNED -	REVISED -
	DRAWN -	REVISED -
PLOT SCALE =	CHECKED -	REVISED -
PLOT DATE =	DATE -	REVISED -


STATE OF ILLINOIS
DEPARTMENT OF TRANSPORTATION



TRAFFIC SIGNAL EQUIPMENT REMOVAL PLAN
IL 64 (NORTH AVE) AND KUHN RD

SCALE: 1" = 20' SHEET OF SHEETS STA. TO STA.

F.A.P. RTE.	SECTION	COUNTY	TOTAL SHEETS	SHEET NO.
307	2020-263-SUR,SW&TS	DUPAGE	529	159
CONTRACT NO. 62N33				
		ILLINOIS	FED. AID PROJECT	

 TS 6445
IDOT TACTICS
FORMER EAGLE 2E



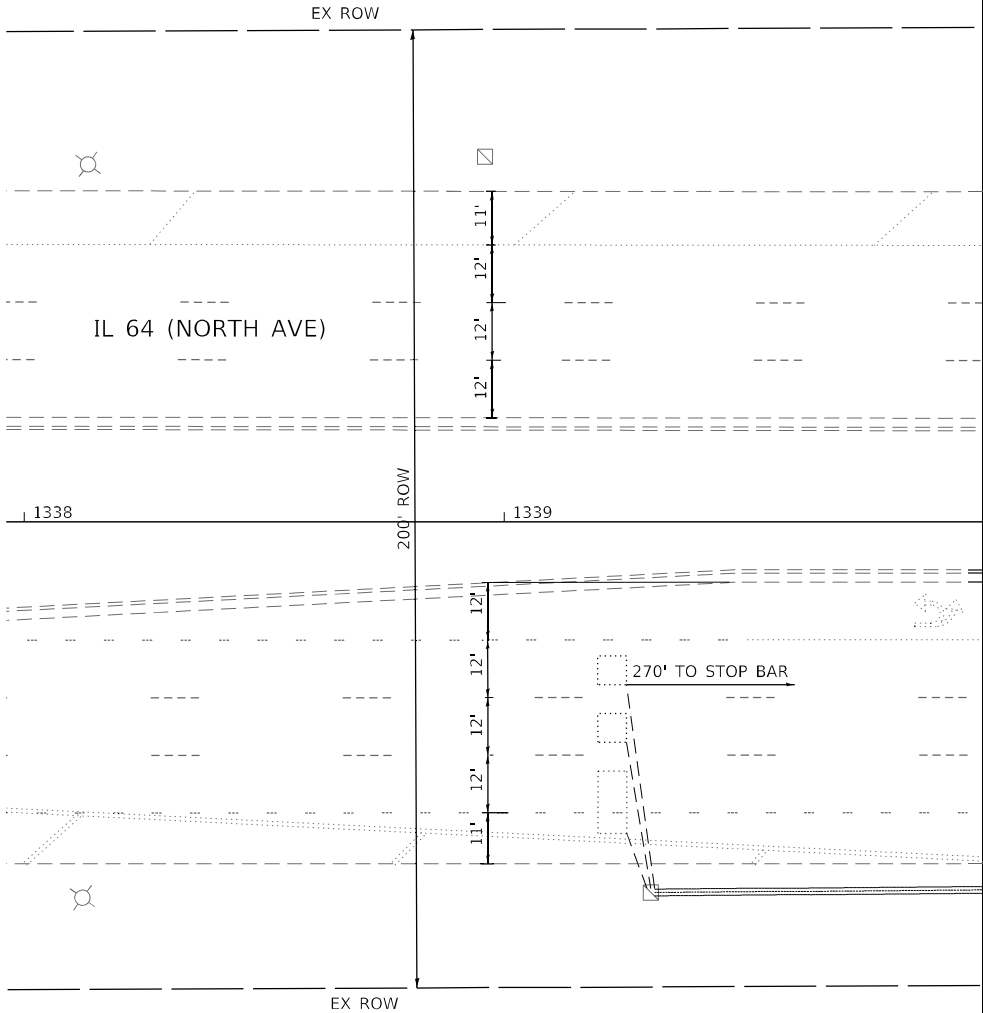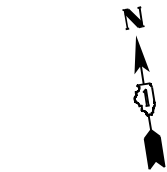

USER NAME =	DESIGNED -	REVISED -
	DRAWN -	REVISED -
PLOT SCALE =	CHECKED -	REVISED -
PLOT DATE =	DATE -	REVISED -

STATE OF ILLINOIS
DEPARTMENT OF TRANSPORTATION

TRAFFIC SIGNAL MODERNIZATION PLAN

IL 64 (NORTH AVE) AND KUHN RD

SCALE: 1" = 20'	SHEET	OF	SHEETS	STA.	TO STA.
-----------------	-------	----	--------	------	---------

F.A.P. RTE.	SECTION	COUNTY	TOTAL SHEETS	SHEET NO.
307	2020-263-SUR,SW&TS	DUPAGE	529	161
		CONTRACT NO. 62N33		
ILLINOIS		FED. AID PROJECT		

SEQUENCE



SEQUENCE



2
6

EX INTERCONNECT TO
COUNTY FARM RD
(TO BE ABANDONED)

EX INTERCONNECT TO
COUNTY FARM RD
(TO BE ABANDONED)

EX TRACER CABLE
(TO BE ABANDONED)

VEHICLE PREEMPTION SEQUENCE



LEGEND:

- ← (⊗) ← PROTECTED PHASE
 ← - (⊗) - PROTECTED/PERMITTED PHASE
 ← (⊗) → PEDESTRIAN PHASE
 ↶ (⊗) ↷ OL OVERLAP

ELECTRICAL SERVICE REQUIREMENTS

TOTAL UPS SIZING

ENERGY SUPPLY: COMPANY: COMED
PHONE: (866) 639-3532
ACCOUNT NUMBER: 29291-26065

ENERGY SUPPLY: COMPANY: COMED
PHONE: (866) 639-3532
ACCOUNT NUMBER: 29291-26065

ACCOUNT NUMBER: 29291-26065

(NOT TO SCALE)



INTERCONNECT TO BENNETT DR/
WINDSOR PARK DR (TO BE ABANDONED)

-EX TRACER CABLE
(TO BE ABANDONED)

IL 64 (NORTH AVE)

TS 6445
IDOT TACTICS
FORMER EAGLE 2E

F.A.P. RTE.	SECTION	COUNTY	TOTAL SHEETS	SHEET NO.
307	2020-263-SUR,SW&TS	DUPAGE	529	162
		CONTRACT NO. 62N33		
ILLINOIS		FED. AID PROJECT		

**STATE OF ILLINOIS
DEPARTMENT OF TRANSPORTATION**

**CABLE PLAN, PHASE DESIGNATION DIAGRAM, AND
EMERGENCY VEHICLE PREEMPTION SEQUENCE
IL 64 (NORTH AVE) AND KUHN RD**

SCALE: N.T.S.	SHEET	OF	SHEETS	STA.	TO STA.
---------------	-------	----	--------	------	---------

Kimley»Horn

© 2023 KIMLEY-HORN AND ASSOCIATES, INC.
4201 WINTERFIELD ROAD, SUITE 603
WARRENVILLE, IL 60555
PHONE: 830-487-5555
WWW.KIMLEY-HORN.COM


MODEL: Default
FILE NAME: pw:\k-f-pw.bentlev.com\kh-pw-01\Documents\01 Active Projects\MW-CHS-169959\100 - IL 64\Phase II\2 Design\CAD\plan Sheets\Signal\West Corridor Signal\10812 L-sht-Ts-61 KHA.dgn

SIGN PANEL – TYPE 1 OR TYPE 2

ALL DIMENSIONS ARE IN INCHES UNLESS OTHERWISE NOTED



DESIGN SERIES	AREA (SQ FT)	SIGN PANEL TYPE	SHEETING TYPE	QTY. REQUIRED
D	12.5	2	ZZ	2

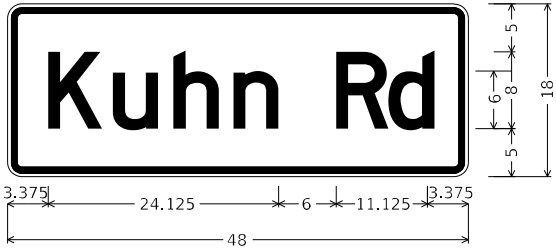

DESIGN SERIES	AREA (SQ FT)	SIGN PANEL TYPE	SHEETING TYPE	QTY. REQUIRED
D	6	1	ZZ	2

SCHEDULE OF QUANTITIES

ITEM DESCRIPTION	UNIT	QUANTITY
SIGN PANEL - TYPE 1	SQ FT	57
SIGN PANEL - TYPE 2	SQ FT	25
UNDERGROUND CONDUIT, GALVANIZED STEEL, 2" DIA.	FOOT	15
UNDERGROUND CONDUIT, GALVANIZED STEEL, 3" DIA.	FOOT	68
UNDERGROUND CONDUIT, GALVANIZED STEEL, 4" DIA.	FOOT	171
MAINTENANCE OF EXISTING TRAFFIC SIGNAL INSTALLATION	EACH	1
ELECTRIC CABLE IN CONDUIT, SIGNAL NO. 14 2C	FOOT	251
ELECTRIC CABLE IN CONDUIT, SIGNAL NO. 14 3C	FOOT	251
ELECTRIC CABLE IN CONDUIT, SIGNAL NO. 14 5C	FOOT	2540
ELECTRIC CABLE IN CONDUIT, SIGNAL NO. 14 7C	FOOT	1270
ELECTRIC CABLE IN CONDUIT, LEAD-IN, NO. 14 1 PAIR	FOOT	1488
ELECTRIC CABLE IN CONDUIT, SERVICE, NO. 6 2 C	FOOT	36
ELECTRIC CABLE IN CONDUIT, EQUIPMENT GROUNDING CONDUCTOR, NO. 6 1C	FOOT	275
TRAFFIC SIGNAL POST, GALVANIZED STEEL 16 FT.	EACH	2
STEEL COMBINATION MAST ARM ASSEMBLY AND POLE 64 FT.	EACH	1
STEEL COMBINATION MAST ARM ASSEMBLY AND POLE 66 FT.	EACH	1
CONCRETE FOUNDATION, TYPE A	FOOT	4
CONCRETE FOUNDATION, TYPE E 42-INCH DIAMETER	FOOT	46
DRILL EXISTING HANDHOLE	EACH	8
SIGNAL HEAD, LED, 1-FACE, 3-SECTION, MAST-ARM MOUNTED	EACH	10
SIGNAL HEAD, LED, 1-FACE, 3-SECTION, BRACKET MOUNTED	EACH	4
SIGNAL HEAD, LED, 1-FACE, 5-SECTION, BRACKET MOUNTED	EACH	4
SIGNAL HEAD, LED, 1-FACE, 5-SECTION, MAST-ARM MOUNTED	EACH	4
PEDESTRIAN SIGNAL HEAD, LED, 1-FACE, BRACKET MOUNTED WITH COUNTDOWN TIMER	EACH	1
TRAFFIC SIGNAL BACKPLATE, LOUVERED, FORMED PLASTIC	EACH	14
INDUCTIVE LOOP DETECTOR	EACH	5
* RELOCATE EXISTING EMERGENCY VEHICLE PRIORITY SYSTEM, DETECTOR UNIT	EACH	2
REMOVE ELECTRIC CABLE FROM CONDUIT	FOOT	6111
REMOVE EXISTING TRAFFIC SIGNAL EQUIPMENT	EACH	1
REMOVE EXISTING CONCRETE FOUNDATION	EACH	2
CLOSED CIRCUIT TELEVISION DOME CAMERA, HD	EACH	1
* EMERGENCY VEHICLE PRIORITY SYSTEM LINE SENSOR CABLE, NO. 20 3/C	FOOT	635
OUTDOOR RATED NETWORK CABLE	FOOT	293
SERVICE INSTALLATION, GROUND MOUNTED, METERED	EACH	1
REMOTE CONTROLLED VIDEO SYSTEM	EACH	1
LAYER II (DATALINK) SWITCH	EACH	1
TERMINATE FIBER IN CABINET	EACH	12
PEDESTRIAN SIGNAL POST, 10 FT.	EACH	1
TACTICS LICENSE EXPANSION	EACH	1
FULL-ACTUATED CONTROLLER IN EXISTING CABINET	EACH	1
REMOVE AND REPLACE BATTERIES FOR UNINTERRUPTABLE POWER SUPPLY, EXTENDED	EACH	1
FIBER OPTIC INTERCONNECT CENTER, 48 PORT	EACH	1
ACCESSIBLE PEDESTRIAN SIGNALS	EACH	1
CONCRETE FOUNDATION, TYPE A 12-INCH DIAMETER	FOOT	4
LED SIGNAL FACE, LENS COVER	EACH	22
VIDEO VEHICLE DETECTION SYSTEM, SINGLE APPROACH	EACH	2
CAMERA MOUNTING ASSEMBLY	EACH	1

* - 100% COST TO THE VILLAGE OF CAROL STREAM

TS 6445
IDOT TACTICS
FORMER EAGLE 2E

MODEL: Default
FILE: \\uslpc-prod\ut-pw-bentley.com\kth-gp-wd\Documents\01 Active Projects\MW-C\US-68959\00 - IL 64\Phase II\2 Design\CAD\Plan_Sheets\Sign\West_Corridor_Signs\B0108171-IL-Rte-62_K4A.dgn

KimleyHorn

© 2023 KIMLEY-HORN AND ASSOCIATES, INC.
4001 WINTER O ROAD, SUITE 600
WARREN, ILL. 60555
PHONE: 847.447.4555
WWW.KIMLEY-HORN.COM

USER NAME =	DESIGNED -	REVISED -
	DRAWN -	REVISED -
PLOT SCALE =	CHECKED -	REVISED -
PLOT DATE =	DATE -	REVISED -

STATE OF ILLINOIS
DEPARTMENT OF TRANSPORTATION

MAST ARM MOUNTED STREET NAME SIGNS AND
SCHEDULE OF QUANTITIES
IL 64 (NORTH AVE) AND KUHN RD


SCALE: N.T.S. SHEET OF SHEETS STA. TO STA.

F.A.P. RTE.	SECTION	COUNTY	TOTAL SHEETS	SHEET NO.
307	2020-263-SUR,SW&TS	DUPAGE	529	163
CONTRACT NO. 62N33				
ILLINOIS FED. AID PROJECT				

NOTES

1. THE EXISTING TRAFFIC SIGNAL EQUIPMENT SHALL NOT BE REMOVED UNTIL THE PROPOSED TRAFFIC SIGNAL EQUIPMENT IS FULLY OPERATIONAL OR AS DIRECTED BY THE ENGINEER.
2. ALL EXISTING TRAFFIC SIGNAL CABLE NO LONGER REQUIRED SHALL BE REMOVED.

MATCH LINE STA 1366+50

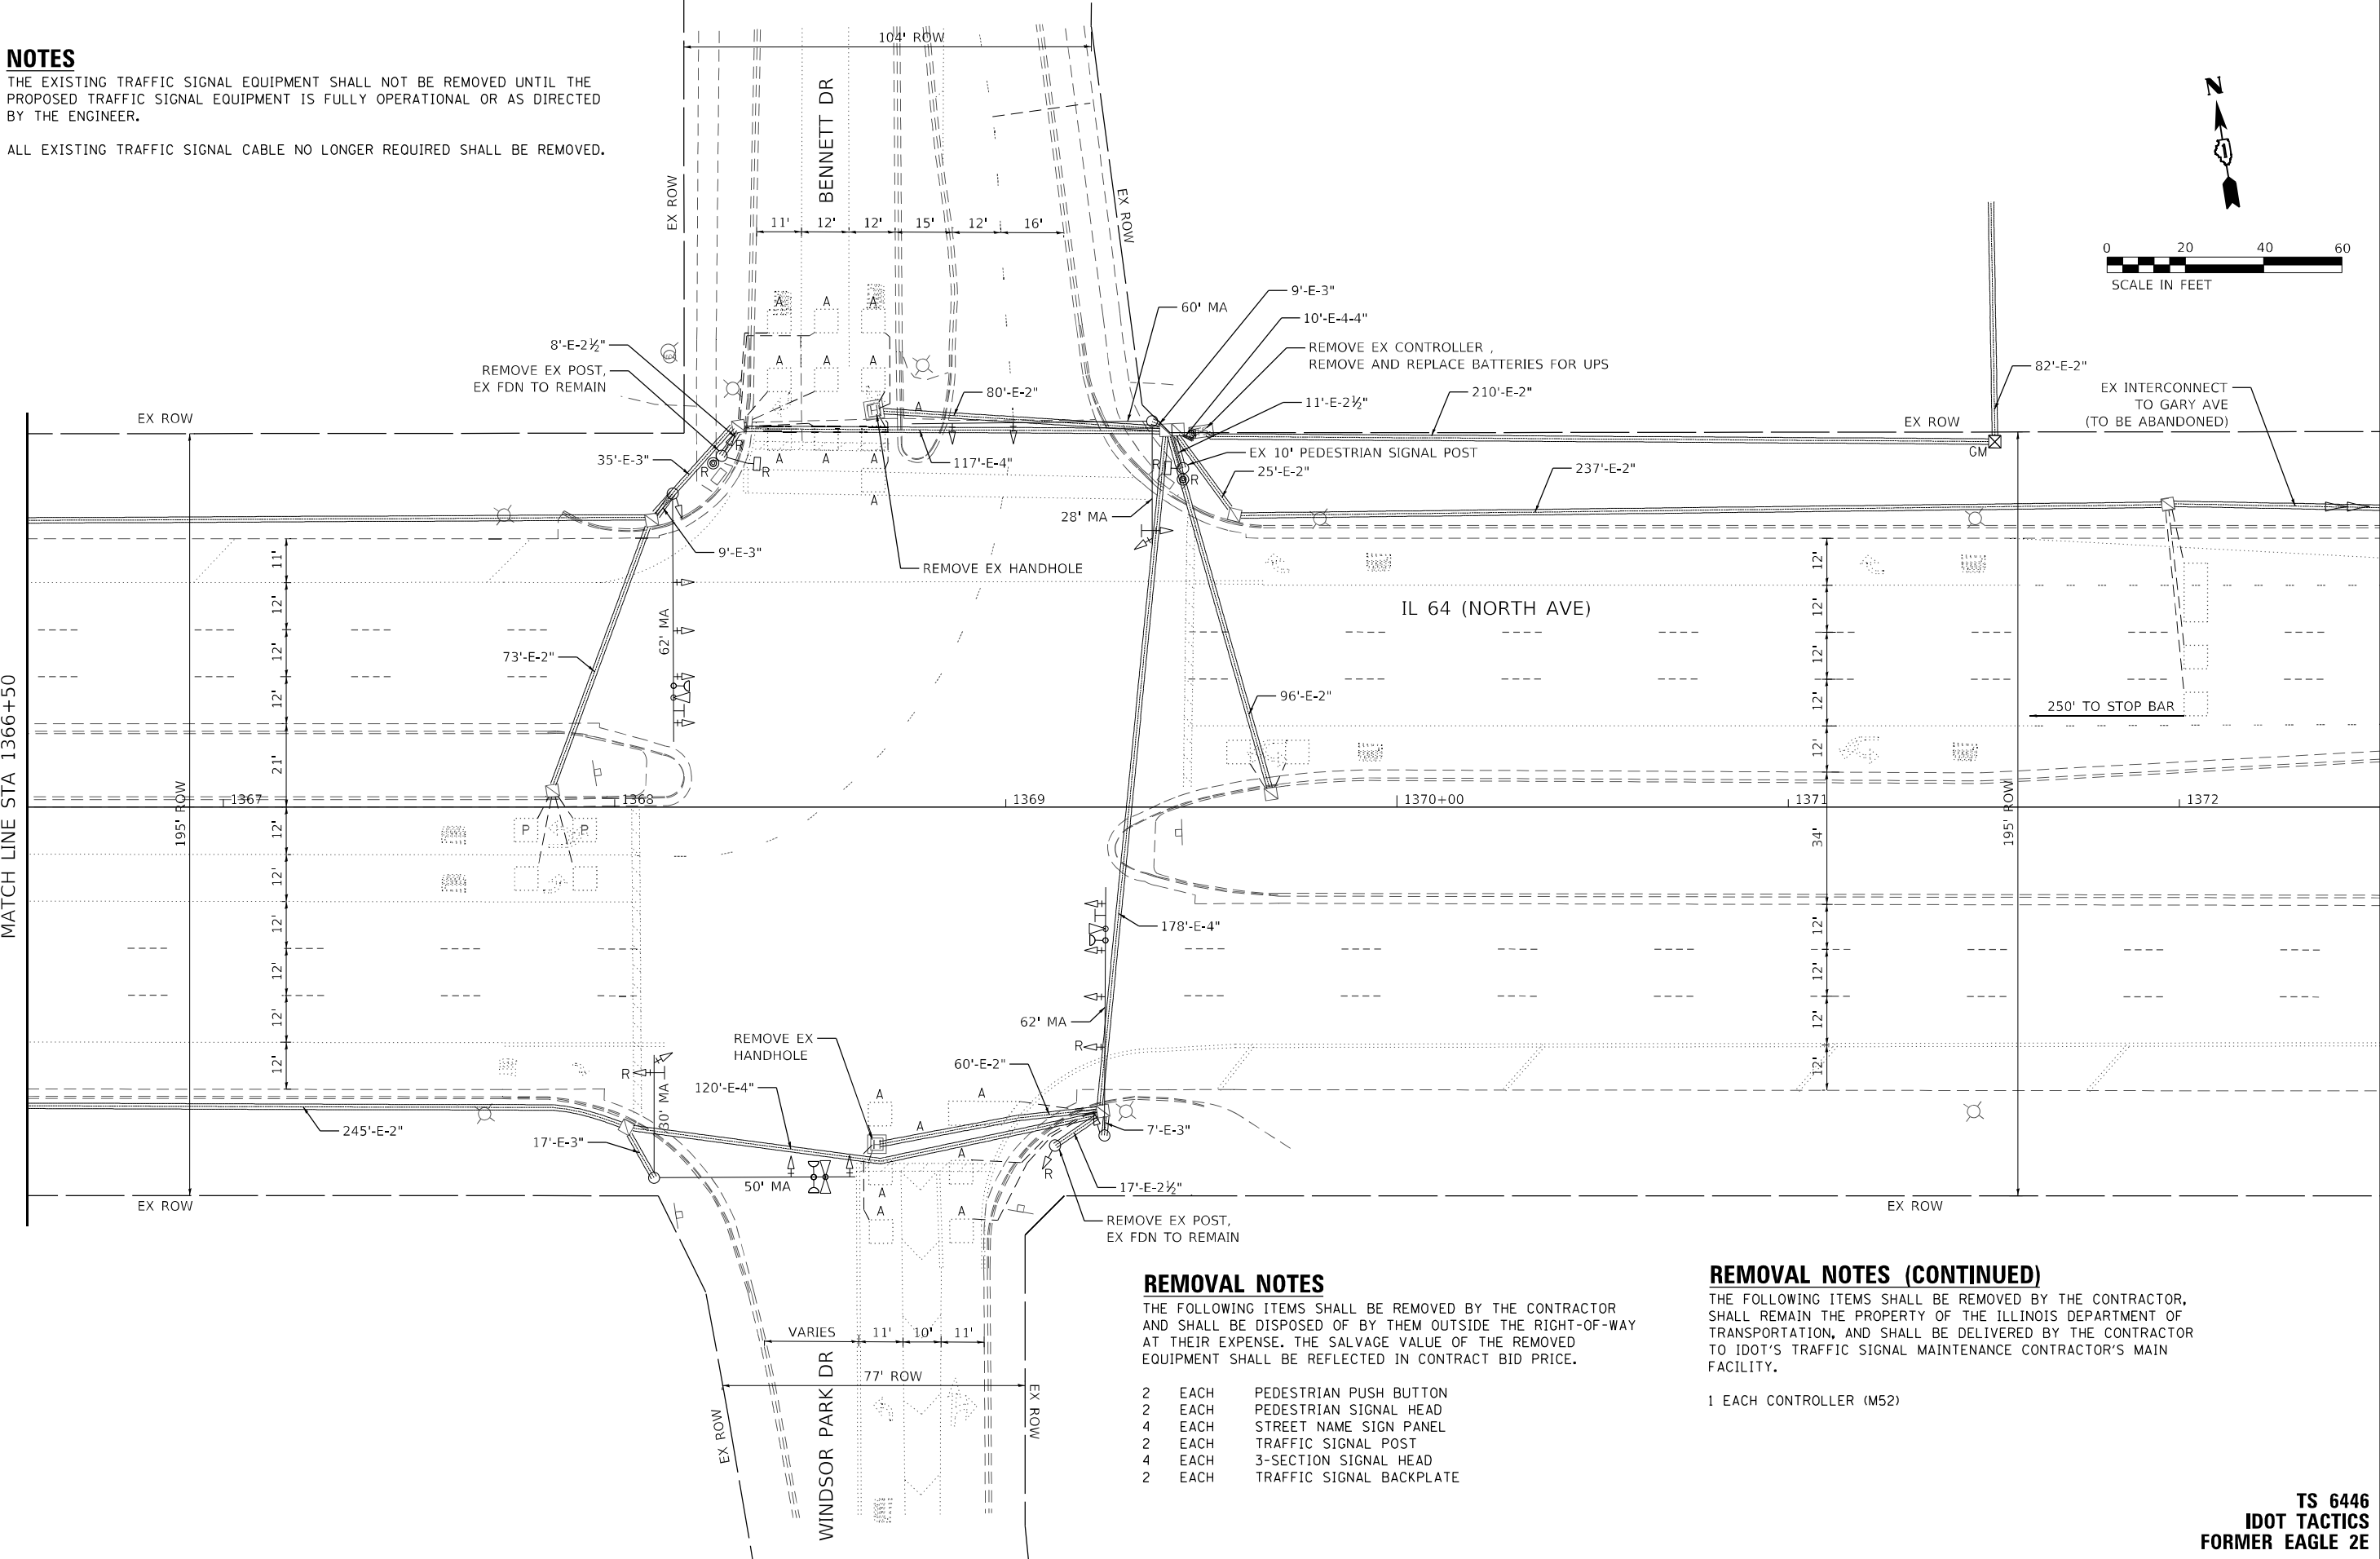

REMOVAL NOTES

THE FOLLOWING ITEMS SHALL BE REMOVED BY THE CONTRACTOR AND SHALL BE DISPOSED OF BY THEM OUTSIDE THE RIGHT-OF-WAY AT THEIR EXPENSE. THE SALVAGE VALUE OF THE REMOVED EQUIPMENT SHALL BE REFLECTED IN CONTRACT BID PRICE.

- | | | |
|---|------|--------------------------|
| 2 | EACH | PEDESTRIAN PUSH BUTTON |
| 2 | EACH | PEDESTRIAN SIGNAL HEAD |
| 4 | EACH | STREET NAME SIGN PANEL |
| 2 | EACH | TRAFFIC SIGNAL POST |
| 4 | EACH | 3-SECTION SIGNAL HEAD |
| 2 | EACH | TRAFFIC SIGNAL BACKPLATE |

REMOVAL NOTES (CONTINUED)

THE FOLLOWING ITEMS SHALL BE REMOVED BY THE CONTRACTOR, SHALL REMAIN THE PROPERTY OF THE ILLINOIS DEPARTMENT OF TRANSPORTATION, AND SHALL BE DELIVERED BY THE CONTRACTOR TO IDOT'S TRAFFIC SIGNAL MAINTENANCE CONTRACTOR'S MAIN FACILITY.

- 1 EACH CONTROLLER (M52)

STATE OF ILLINOIS
DEPARTMENT OF TRANSPORTATION

TRAFFIC SIGNAL EQUIPMENT REMOVAL PLAN
IL 64 (NORTH AVE) AND BENNETT DR/WINDSOR PARK DR

SCALE: 1" = 20' SHEET OF SHEETS STA. TO STA.

F.A.P. RTE.	SECTION	COUNTY	TOTAL SHEETS	SHEET NO.
307	2020-263-SUR,SW&TS	DUPAGE	529	164
CONTRACT NO. 62N33				
ILLINOIS FED. AID PROJECT				



TS 6446
IDOT TACTICS
FORMER EAGLE 2E

KimleyHorn

© 2021 KIMLEY-HORN AND ASSOCIATES, INC.
4001 WILSON ROAD, SUITE 600
WARREN, ILL. 60555
PHONE: (847) 455-1000
WWW.KIMLEY-HORN.COM

USER NAME	=	DESIGNED	-
DRAWN	-	REVIS	-
PLOT SCALE	=	CHECKED	-
PLOT DATE	=	DATE	-

REVIS	-
REVIS	-
REVIS	-
REVIS	-

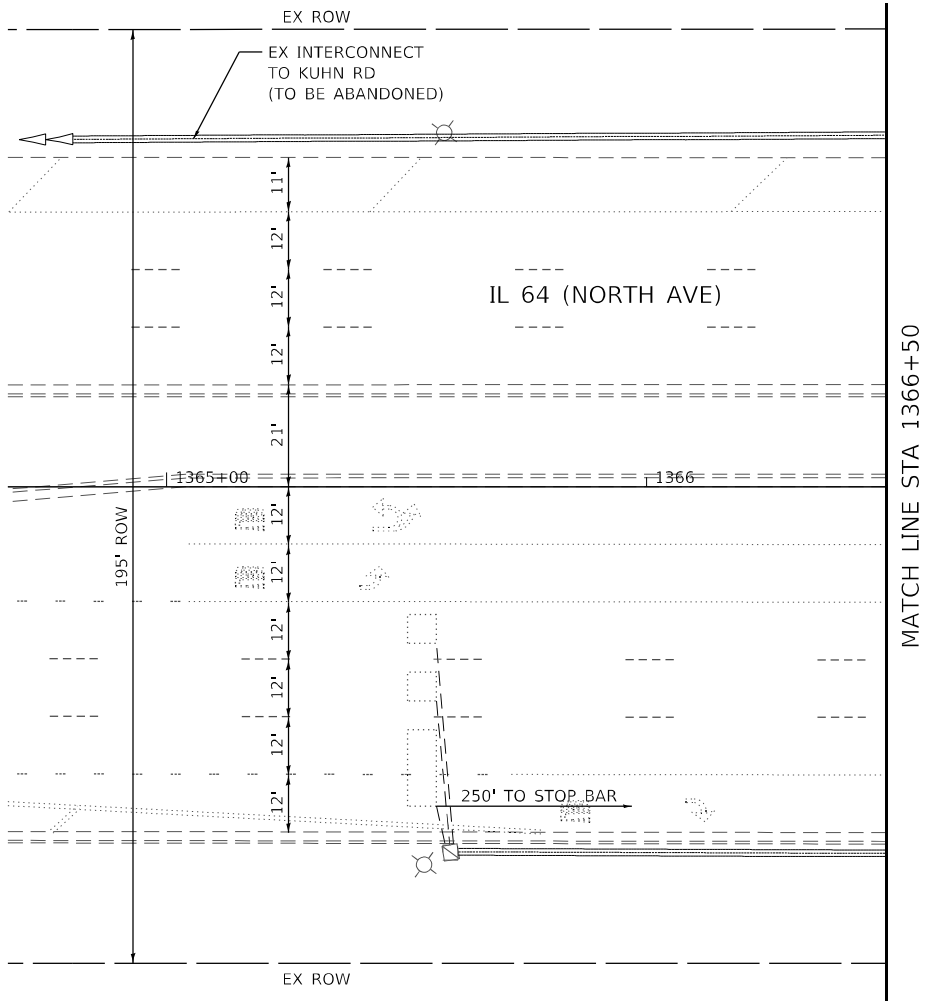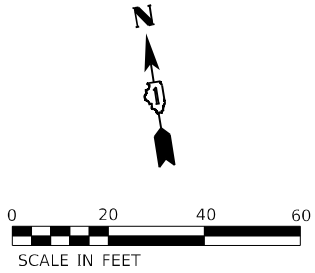

TS 6446
IDOT TACTICS
FORMER EAGLE 2E



© 2023 KIMLEY-HORN AND ASSOCIATES, INC.
4001 WHITE OAK ROAD, SUITE 600
WARREN, ILL. 60555
PHONE: 815.447.4555
WWW.KIMLEY-HORN.COM


USER NAME =	DESIGNED -	REVISED -
	DRAWN -	REVISED -
PLOT SCALE =	CHECKED -	REVISED -
PLOT DATE =	DATE -	REVISED -

STATE OF ILLINOIS
DEPARTMENT OF TRANSPORTATION

TRAFFIC SIGNAL EQUIPMENT REMOVAL PLAN
IL 64 (NORTH AVE) AND BENNETT DR / WINDSOR PARK DR


SCALE: 1" = 20' SHEET OF SHEETS STA. TO STA.

F.A.P. RTE.	SECTION	COUNTY	TOTAL SHEETS	SHEET NO.
307	2020-263-SUR, SW&TS	DUPAGE	529	165
CONTRACT NO. 62N33				
		ILLINOIS	FED. AID PROJECT	

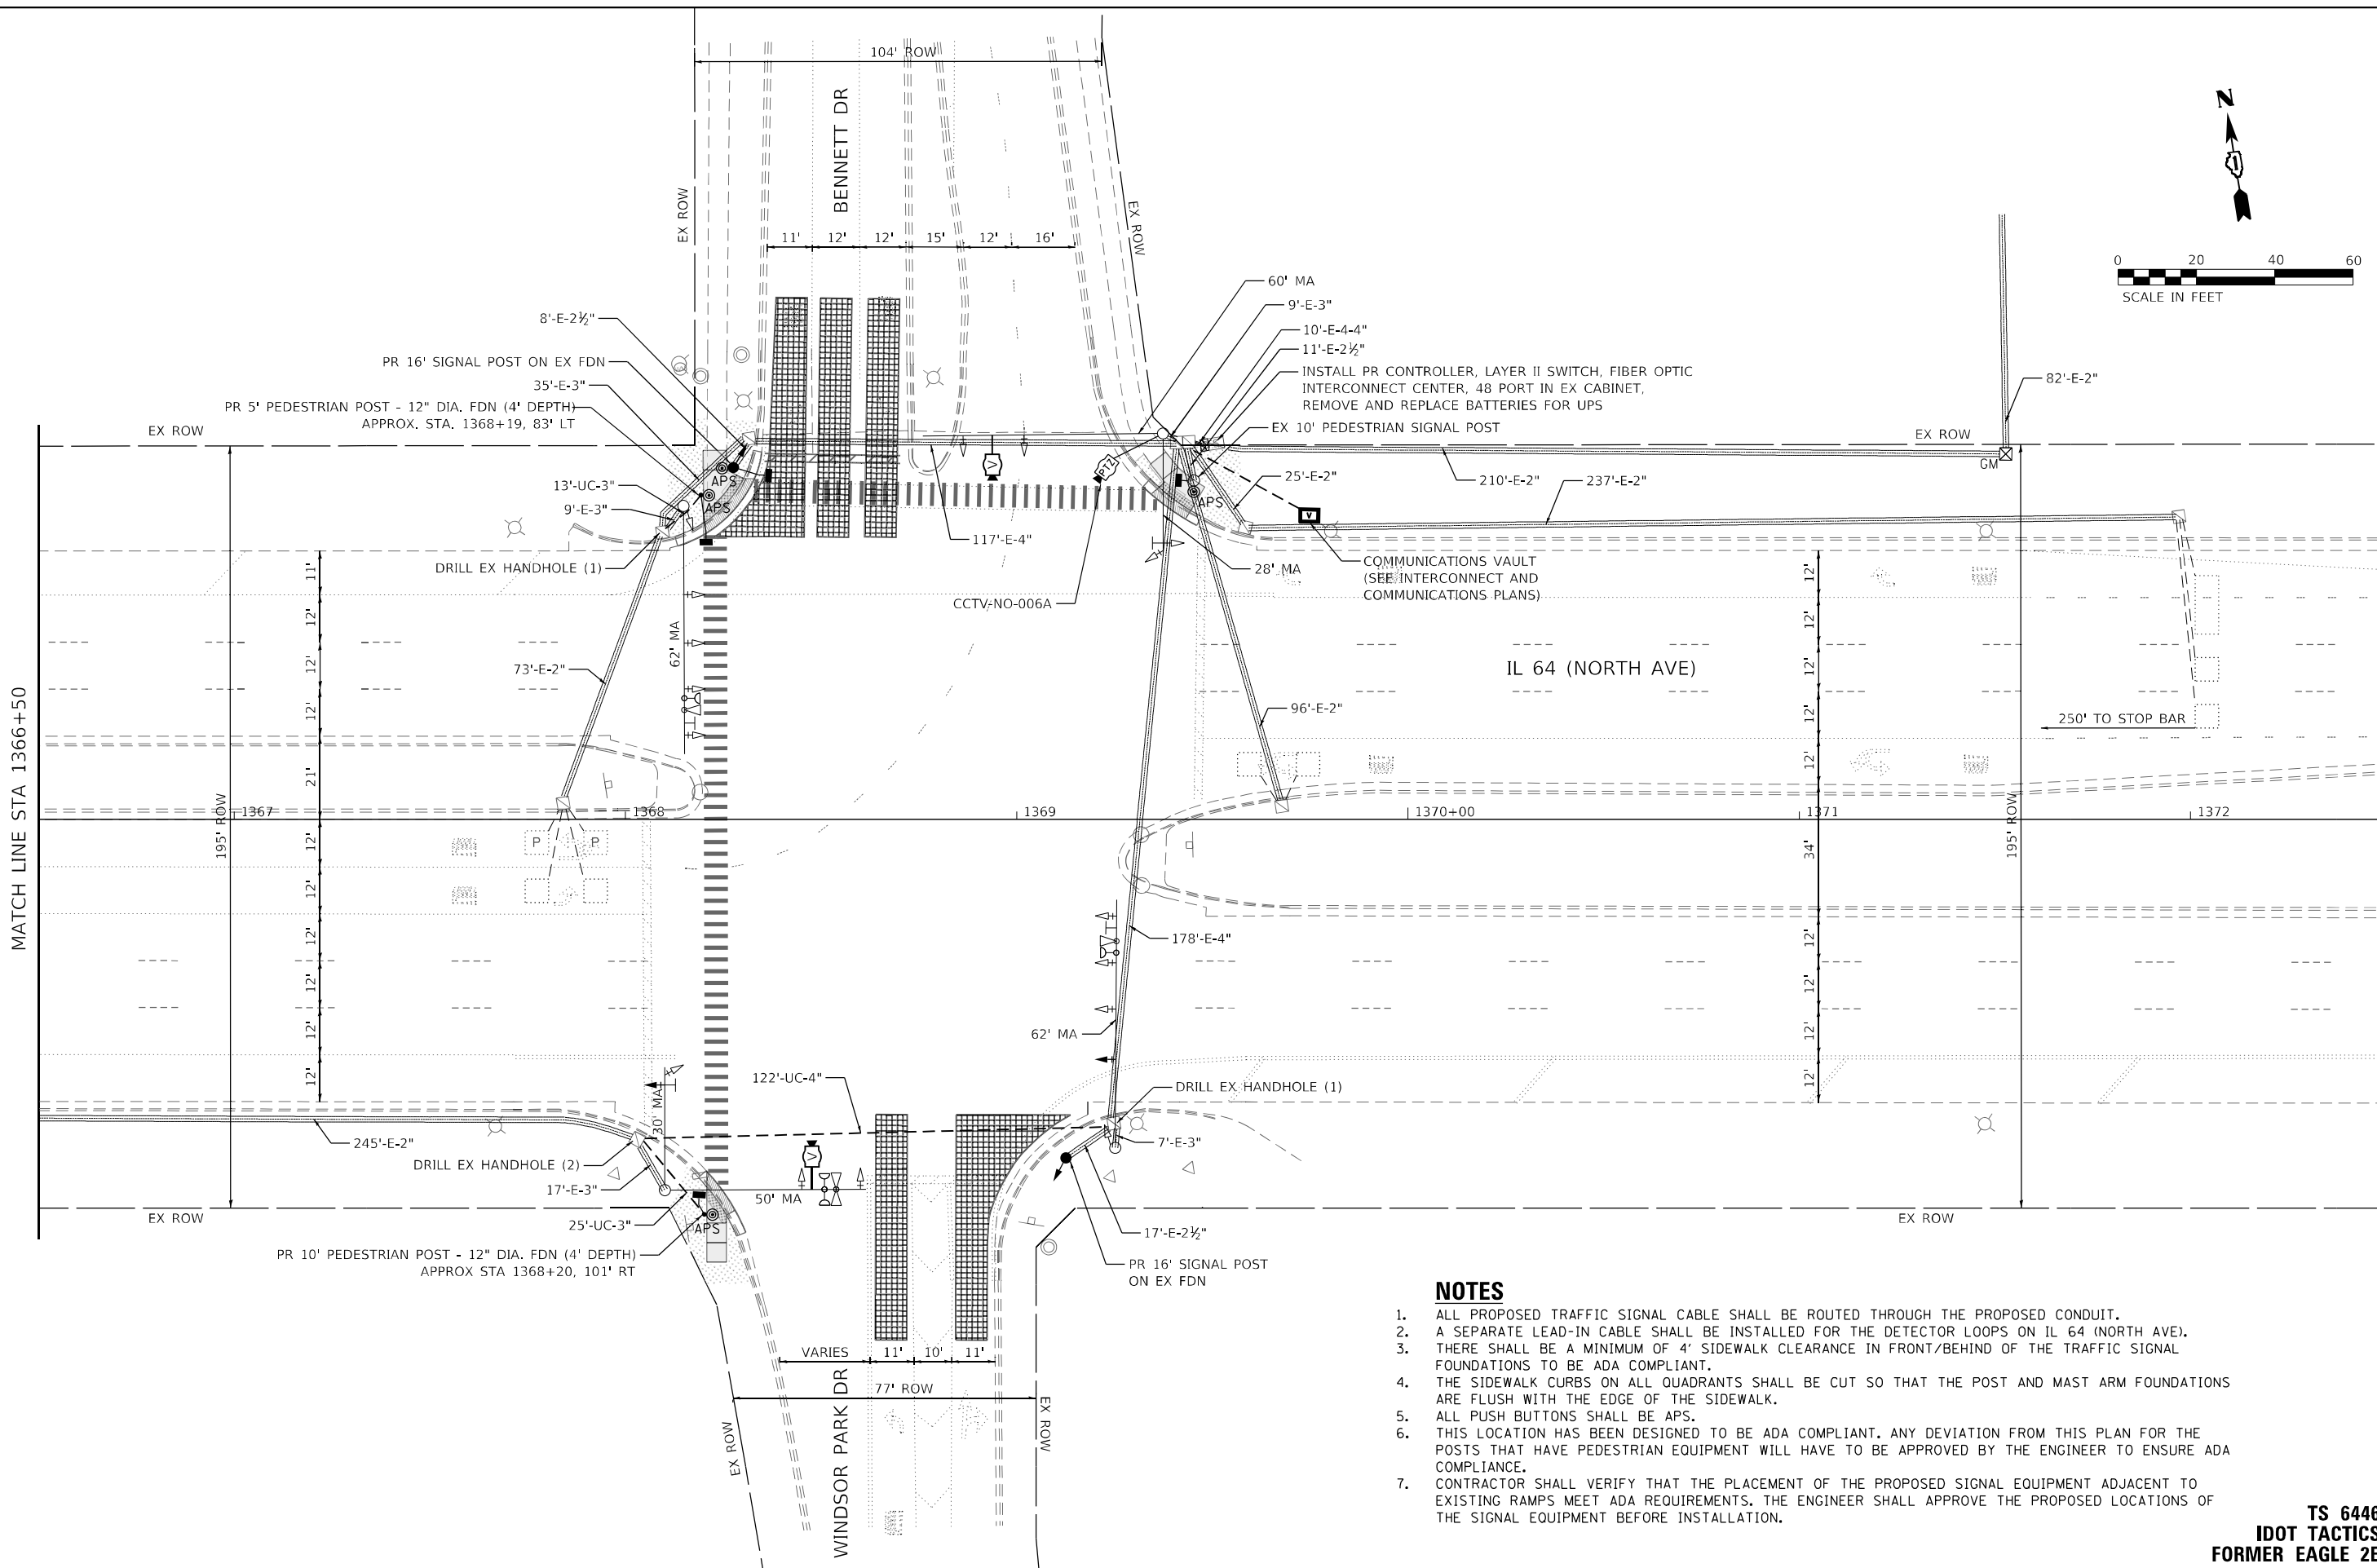

- ## **NOTES**
1. ALL PROPOSED TRAFFIC SIGNAL CABLE SHALL BE ROUTED THROUGH THE PROPOSED CONDUIT.
 2. A SEPARATE LEAD-IN CABLE SHALL BE INSTALLED FOR THE DETECTOR LOOPS ON IL 64 (NORTH AVE).
 3. THERE SHALL BE A MINIMUM OF 4' SIDEWALK CLEARANCE IN FRONT/BEHIND OF THE TRAFFIC SIGNAL FOUNDATIONS TO BE ADA COMPLIANT.
 4. THE SIDEWALK CURBS ON ALL QUADRANTS SHALL BE CUT SO THAT THE POST AND MAST ARM FOUNDATIONS ARE FLUSH WITH THE EDGE OF THE SIDEWALK.
 5. ALL PUSH BUTTONS SHALL BE APS.
 6. THIS LOCATION HAS BEEN DESIGNED TO BE ADA COMPLIANT. ANY DEVIATION FROM THIS PLAN FOR THE POSTS THAT HAVE PEDESTRIAN EQUIPMENT WILL HAVE TO BE APPROVED BY THE ENGINEER TO ENSURE ADA COMPLIANCE.
 7. CONTRACTOR SHALL VERIFY THAT THE PLACEMENT OF THE PROPOSED SIGNAL EQUIPMENT ADJACENT TO EXISTING RAMPS MEET ADA REQUIREMENTS. THE ENGINEER SHALL APPROVE THE PROPOSED LOCATIONS OF THE SIGNAL EQUIPMENT BEFORE INSTALLATION.

TS 6446
IDOT TACTICS
FORMER EAGLE 2E

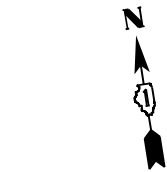

IL 64 (NORTH AVE)

MATCH LINE STA 1366+50

250' TO STOP BAR

EX ROW

STATE OF ILLINOIS
DEPARTMENT OF TRANSPORTATION

TRAFFIC SIGNAL MODERNIZATION PLAN


IL 64 (NORTH AVE) AND BENNETT DR/WINDSOR PARK DR

F.A.P. RTE.	SECTION	COUNTY	TOTAL SHEETS	SHEET NO.
307	2020-263-SUR,SW&TS	DUPAGE	529	167
		CONTRACT NO. 62N33		
ILLINOIS		FED. AID PROJECT		


**TS 6446
IDOT TACTICS
FORMER EAGLE 2E**

MODEL: Default


EXISTING CONTROLLER SEQUENCE

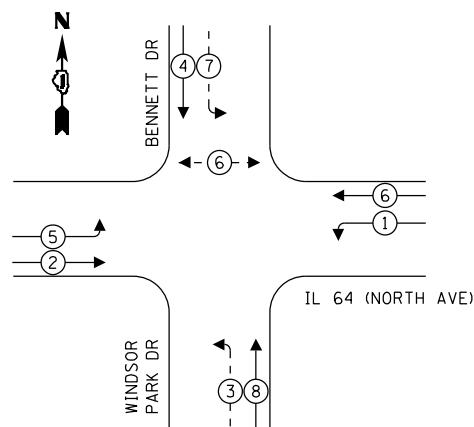

PROPOSED CONTROLLER SEQUENCE

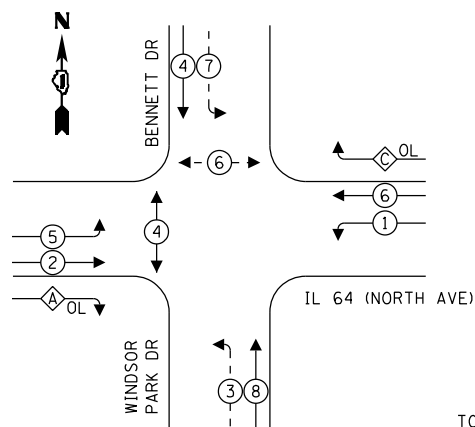

EXISTING AND PROPOSED EMERGENCY VEHICLE PREEMPTION SEQUENCE

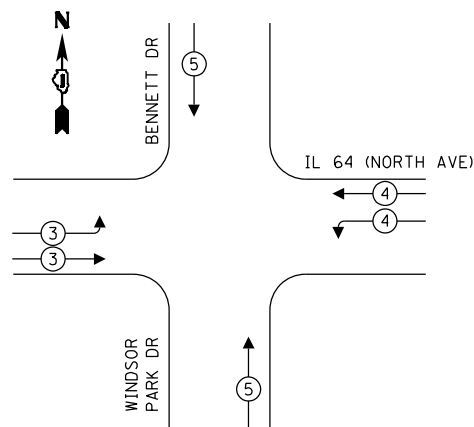

LEGEND:

-  PROTECTED PHASE
 PROTECTED/PERMITTED PHASE
 PEDESTRIAN PHASE
 OVERLAP

OVERLAP <u>LETTER</u>		PERMISSIVE <u>PHASE</u>		PROTECTED <u>PHASE</u>
C	=	6	+	7
A	=	2	+	3

TRAFFIC SIGNAL ELECTRICAL SERVICE REQUIREMENTS


TYPE	QUANTITY	UNIT WATTAGE	TOTAL WATTAGE
SIGNAL HEAD 1 OR 3-SECTION	12	11	132
4-SECTION	-	14	-
5-SECTION	8	13	104
PROGRAMMABLE 3-SECTION	-	22	-
4-SECTION	-	32	-
5-SECTION	-	28	-
PEDESTRIAN SIGNAL	4	15	60
CONTROLLER	1	150	150
MASTER CONTROLLER	-	100	-
UPS	1	25	25
DETECTION VIDEO	2	20	40
BLANK-OUT SIGN	-	25	-
NETWORK SWITCH LAYER II OR III	1	35	35
CELLULAR MODEM	-	15	-
PTZ	1	75	75
TOTAL UPS SIZING			621
UPS CHARGING	1	225	225
BATTERY HEATER MAT	1	180	180
CABINET HEATER	1	200	200
FLASHER	-	15	-
LED STREET NAME SIGN	-	120	-
LUMINAIRE	-	240	-
TOTAL SERVICE WIRE SIZING			1226

ENERGY COSTS TO: ILLINOIS DEPARTMENT OF TRANSPORTATION 201 W CENTER CT SCHAUMBURG, IL 60196
--

ENERGY SUPPLY: COMPANY: COMED
PHONE: (866) 639-3532
ACCOUNT NUMBER: 29291-26065

LEGEND:

L = LED LAMP MODULE REPLACEMENT

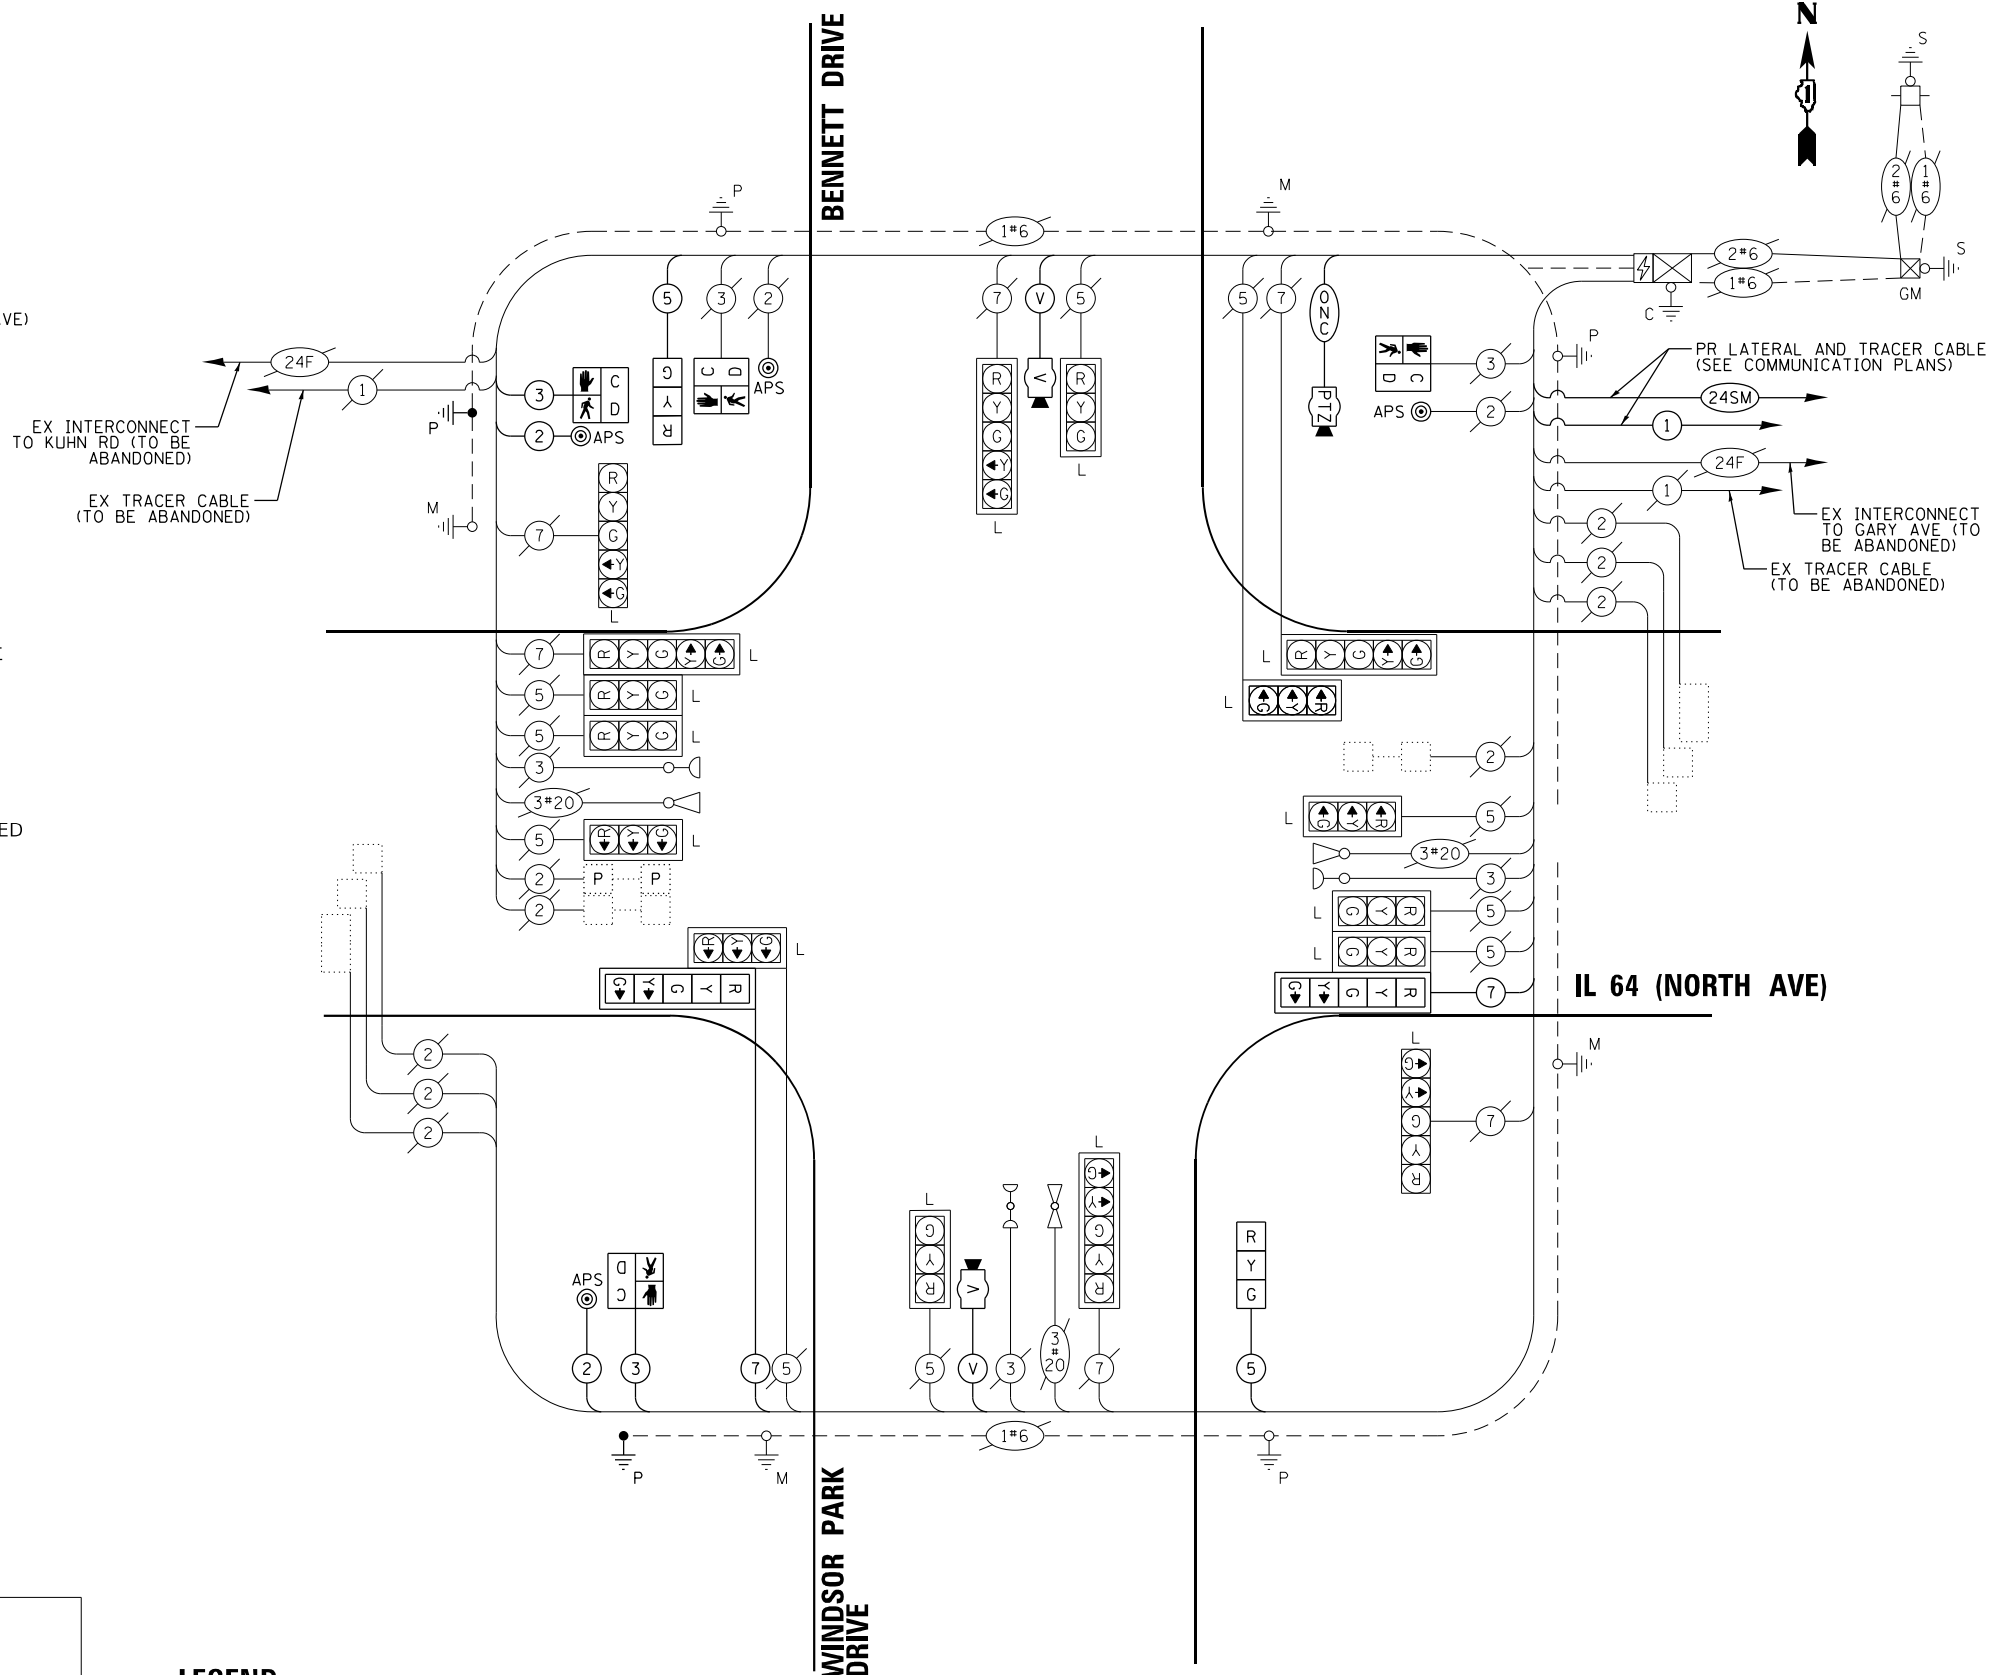

CABLE PLAN

(NOT TO SCALE)

**TS 6446
IDOT TACTICS
FORMER EAGLE 2E**

F.A.P. RTE.	SECTION	COUNTY	TOTAL SHEETS	SHEET NO.
307	2020-263-SUR, SW&TS	DUPAGE	529	168
		CONTRACT NO. 62N33		
		ILLINOIS	FED. AID PROJECT	

**STATE OF ILLINOIS
DEPARTMENT OF TRANSPORTATION**

**CABLE PLAN, PHASE DESIGNATION DIAGRAM, AND
EMERGENCY VEHICLE PREEMPTION SEQUENCE
64 (NORTH AVE) AND BENNETT DR/WINDSOR PARK DR**

SCALE: N.T.S.	SHEET	OF	SHEETS	STA.	TO STA.
---------------	-------	----	--------	------	---------

Kimley»»Horn

© 2023 KIMLEY-HORN AND ASSOCIATES, INC.
4201 WINFIELD ROAD, SUITE 603
WARREN, IL 60555
PHONE: 830-487-6550
WWW.KIMLEY-HORN.COM


MODEL: Default
 EPI F NAME: newWeb-new.bentley.com\k-hw-01\Documents\01_Active_Projects\MM-CHS-168959100 - II_64\Phase II\2_Desim\CAMPlan_Sheers\Sinks\West_Corridor_Signaled\108121-sht-5-67_KHA.dgn

SIGN PANEL – TYPE 2


ALL DIMENSIONS ARE IN INCHES UNLESS OTHERWISE NOTED



DESIGN SERIES	AREA (SQ FT)	SIGN PANEL TYPE	SHEETING TYPE	QTY. REQUIRED
D	12.5	2	ZZ	2

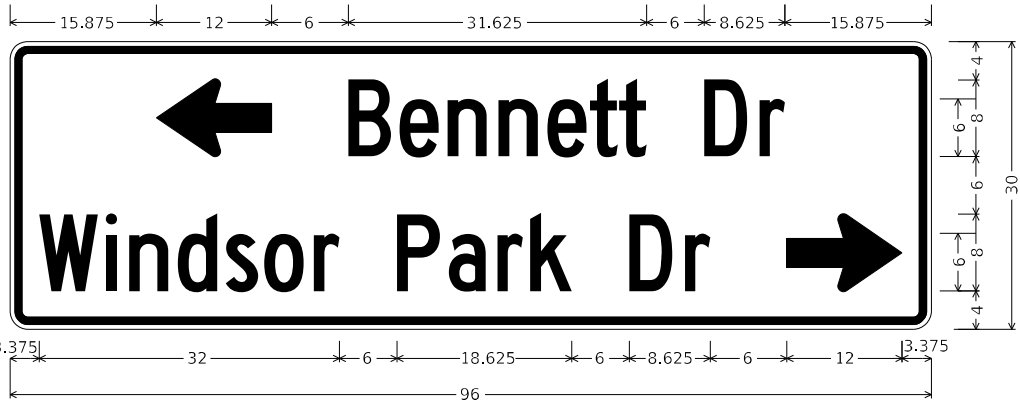

DESIGN SERIES	AREA (SQ FT)	SIGN PANEL TYPE	SHEETING TYPE	QTY. REQUIRED
C	20	2	ZZ	1

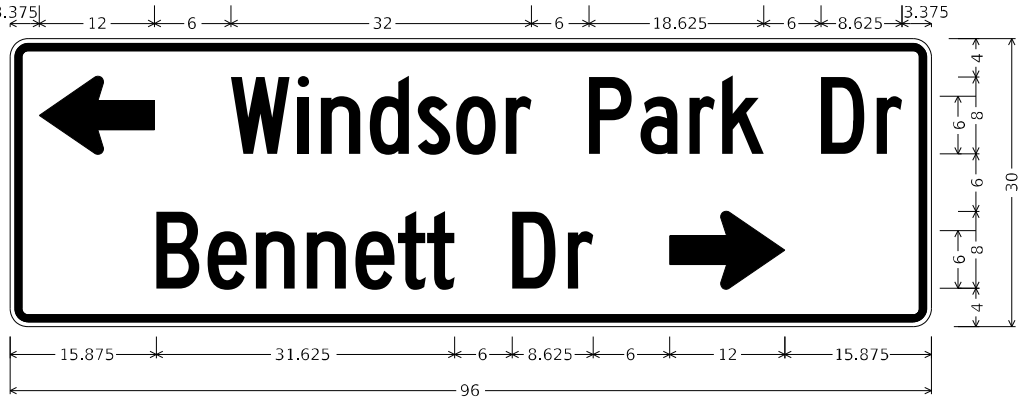

DESIGN SERIES	AREA (SQ FT)	SIGN PANEL TYPE	SHEETING TYPE	QTY. REQUIRED
C	20	2	ZZ	1

SCHEDULE OF QUANTITIES

ITEM DESCRIPTION	UNIT	QUANTITY
SIGN PANEL - TYPE 2	SQ FT	65
UNDERGROUND CONDUIT, GALVANIZED STEEL, 3" DIA.	FOOT	38
UNDERGROUND CONDUIT, GALVANIZED STEEL, 4" DIA.	FOOT	122
MAINTENANCE OF EXISTING TRAFFIC SIGNAL INSTALLATION	EACH	1
ELECTRIC CABLE IN CONDUIT, SIGNAL NO. 14 2C	FOOT	581
ELECTRIC CABLE IN CONDUIT, SIGNAL NO. 14 3C	FOOT	581
ELECTRIC CABLE IN CONDUIT, SIGNAL NO. 14 7C	FOOT	417
ELECTRIC CABLE IN CONDUIT, EQUIPMENT GROUNDING CONDUCTOR, NO. 6 1C	FOOT	160
TRAFFIC SIGNAL POST, GALVANIZED STEEL 16 FT.	EACH	2
DRILL EXISTING HANDHOLE	EACH	4
SIGNAL HEAD, LED, 1-FACE, 3-SECTION, BRACKET MOUNTED	EACH	2
SIGNAL HEAD, LED, 1-FACE, 5-SECTION, MAST-ARM MOUNTED	EACH	2
PEDESTRIAN SIGNAL HEAD, LED, 1-FACE, BRACKET MOUNTED WITH COUNTDOWN TIMER	EACH	4
TRAFFIC SIGNAL BACKPLATE, LOUVERED, FORMED PLASTIC	EACH	2
REMOVE ELECTRIC CABLE FROM CONDUIT	FOOT	1739
REMOVE EXISTING TRAFFIC SIGNAL EQUIPMENT	EACH	1
REMOVE EXISTING HANDHOLE	EACH	2
CLOSED CIRCUIT TELEVISION DOME CAMERA, HD	EACH	1
OUTDOOR RATED NETWORK CABLE	FOOT	94
REMOTE CONTROLLED VIDEO SYSTEM	EACH	1
LAYER II (DATALINK) SWITCH	EACH	1
TERMINATE FIBER IN CABINET	EACH	12
PEDESTRIAN SIGNAL POST, 10 FT.	EACH	1
PEDESTRIAN SIGNAL POST, 5 FT.	EACH	1
TACTICS LICENSE EXPANSION	EACH	1
FULL-ACTUATED CONTROLLER IN EXISTING CABINET	EACH	1
REMOVE AND REPLACE BATTERIES FOR UNINTERRUPTABLE POWER SUPPLY, EXTENDED	EACH	1
FIBER OPTIC INTERCONNECT CENTER, 48 PORT	EACH	1
ACCESSIBLE PEDESTRIAN SIGNALS	EACH	4
CONCRETE FOUNDATION, TYPE A 12-INCH DIAMETER	FOOT	8
LED SIGNAL MODULE REPLACEMENT	EACH	60
LED SIGNAL FACE, LENS COVER	EACH	20
VIDEO VEHICLE DETECTION SYSTEM, SINGLE APPROACH	EACH	2
CAMERA MOUNTING ASSEMBLY	EACH	1

TS 6446
IDOT TACTICS
FORMER EAGLE 2E

MODEL: Default
FILE: I:\MISC_projects\pvt_bentley.com\ktp\p4\1\Documents\01_Active_Projects\MW-Ch-S-16895\0100 - IL_64\Phase_III\2_Design\CAD\Plan_Sheets\Sign\West_Corridor_Sign\BID\081714-nt-ts-68_K4A.dgn

Kimley»Horn

© 2023 KIMLEY-HORN AND ASSOCIATES, INC.
4001 HWY 10, SUITE 400
WARREN, IL 60555
PHONE: 847.447.4555
WWW.KH-IL.COM

USER NAME =
PLOT SCALE =
PLOT DATE =

DESIGNED -
DRAWN -
CHECKED -
DATE -

REVISED -
REVISED -
REVISED -
REVISED -

STATE OF ILLINOIS
DEPARTMENT OF TRANSPORTATION


SCHEDULE OF QUANTITIES
IL 64 (NORTH AVE) AND BENNETT DR/WINDSOR PARK DR

SCALE: N.T.S. SHEET OF SHEETS STA. TO STA.

F.A.P. RTE.	SECTION	COUNTY	TOTAL SHEETS	SHEET NO.
307	2020-263-SUR,SW&TS	DUPAGE	529	169
CONTRACT NO. 62N33				
ILLINOIS FED. AID PROJECT				

NOTES

1. THE EXISTING TRAFFIC SIGNAL EQUIPMENT SHALL NOT BE REMOVED UNTIL THE PROPOSED TRAFFIC SIGNAL EQUIPMENT IS FULLY OPERATIONAL OR AS DIRECTED BY THE ENGINEER.
2. ALL EXISTING TRAFFIC SIGNAL CABLE NO LONGER REQUIRED SHALL BE REMOVED.

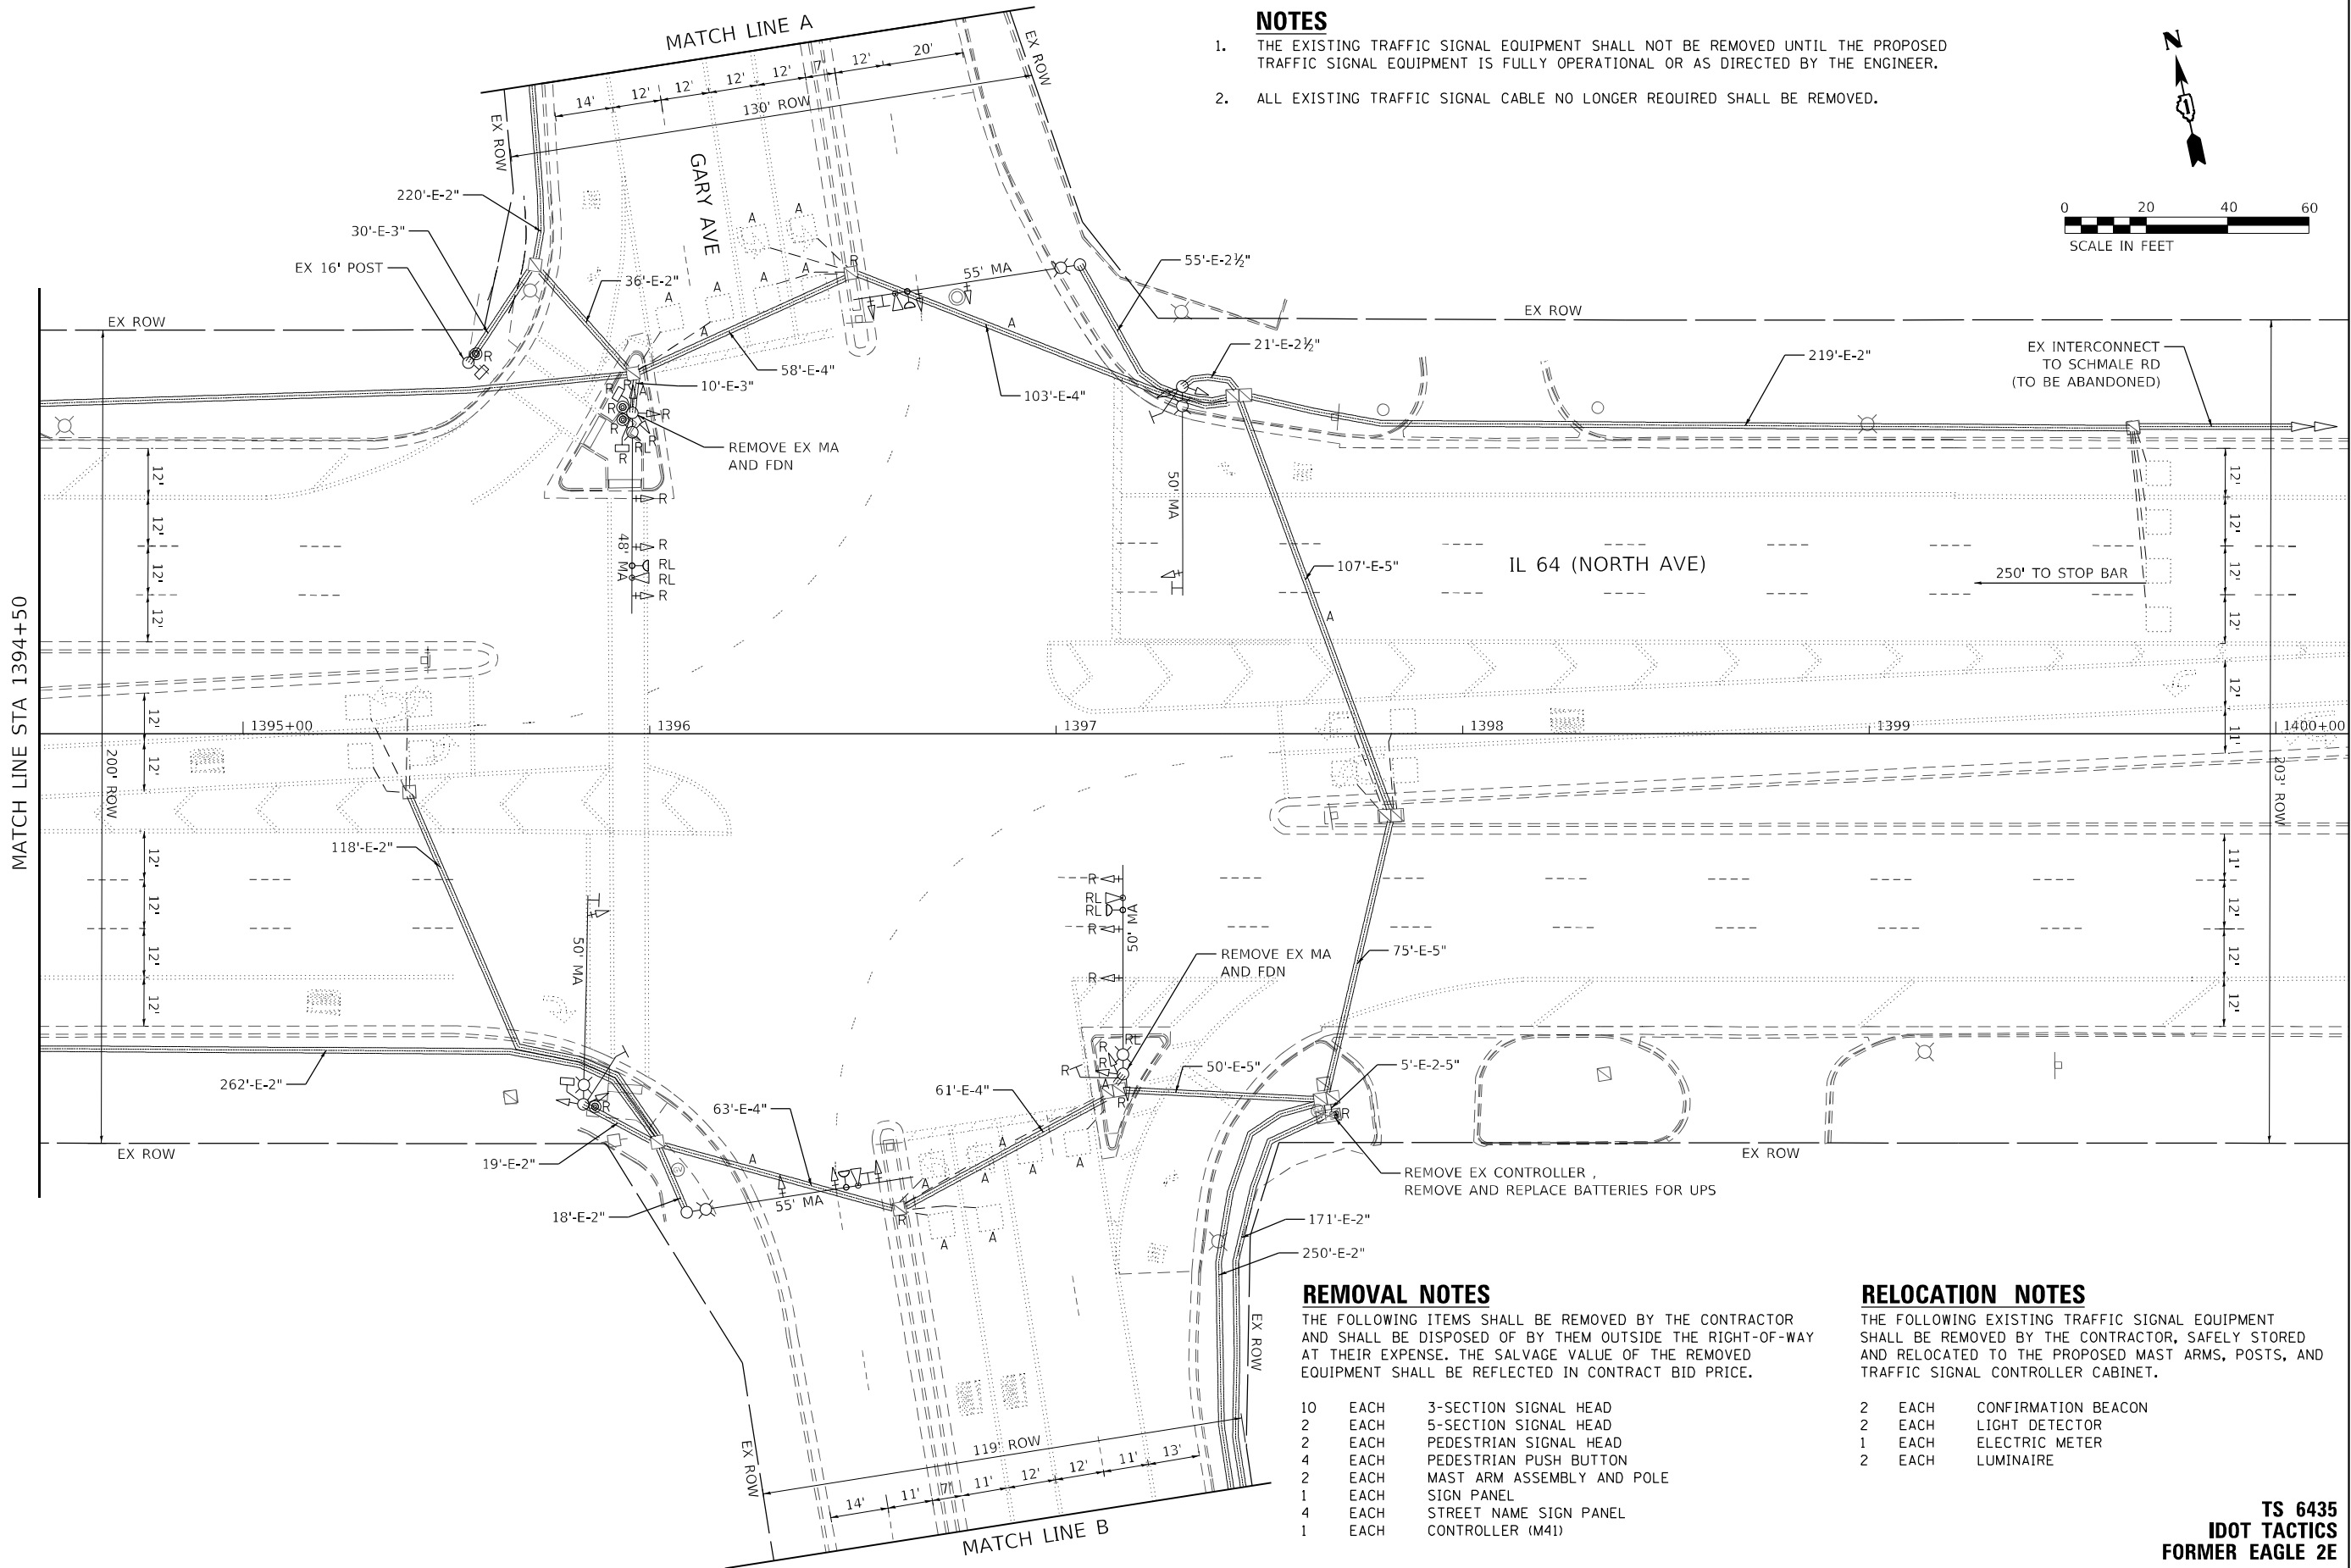

REMOVAL NOTES

THE FOLLOWING ITEMS SHALL BE REMOVED BY THE CONTRACTOR AND SHALL BE DISPOSED OF BY THEM OUTSIDE THE RIGHT-OF-WAY AT THEIR EXPENSE. THE SALVAGE VALUE OF THE REMOVED EQUIPMENT SHALL BE REFLECTED IN CONTRACT BID PRICE.

10	EACH	3-SECTION SIGNAL HEAD
2	EACH	5-SECTION SIGNAL HEAD
2	EACH	PEDESTRIAN SIGNAL HEAD
4	EACH	PEDESTRIAN PUSH BUTTON
2	EACH	MAST ARM ASSEMBLY AND POLE
1	EACH	SIGN PANEL
4	EACH	STREET NAME SIGN PANEL
1	EACH	CONTROLLER (M41)

RELOCATION NOTES

THE FOLLOWING EXISTING TRAFFIC SIGNAL EQUIPMENT SHALL BE REMOVED BY THE CONTRACTOR, SAFELY STORED AND RELOCATED TO THE PROPOSED MAST ARMS, POSTS, AND TRAFFIC SIGNAL CONTROLLER CABINET.

2	EACH	CONFIRMATION BEACON
2	EACH	LIGHT DETECTOR
1	EACH	ELECTRIC METER
2	EACH	LUMINAIRE

STATE OF ILLINOIS
DEPARTMENT OF TRANSPORTATION

TRAFFIC SIGNAL EQUIPMENT REMOVAL PLAN
IL 64 (NORTH AVE) AND GARY AVE

SCALE: 1" = 20' SHEET OF SHEETS STA. TO STA.


F.A.P. RTE.	SECTION	COUNTY	TOTAL SHEETS	SHEET NO.
307	2020-263-SUR, SW&TS	DUPAGE	529	170
				CONTRACT NO. 62N33
ILLINOIS		FED. AID PROJECT		

TS 6435
IDOT TACTICS
FORMER EAGLE 2E

KimleyHorn

© 2021 KIMLEY-HORN AND ASSOCIATES, INC.
4001 WILMINGTON ROAD, SUITE 600
WARREN, ILL. 60555
PHONE: 815.447.4555
WWW.KIMLEY-HORN.COM

USER NAME =	DESIGNED -	REVISED -
	DRAWN -	REVISED -
PLOT SCALE =	CHECKED -	REVISED -
PLOT DATE =	DATE -	REVISED -

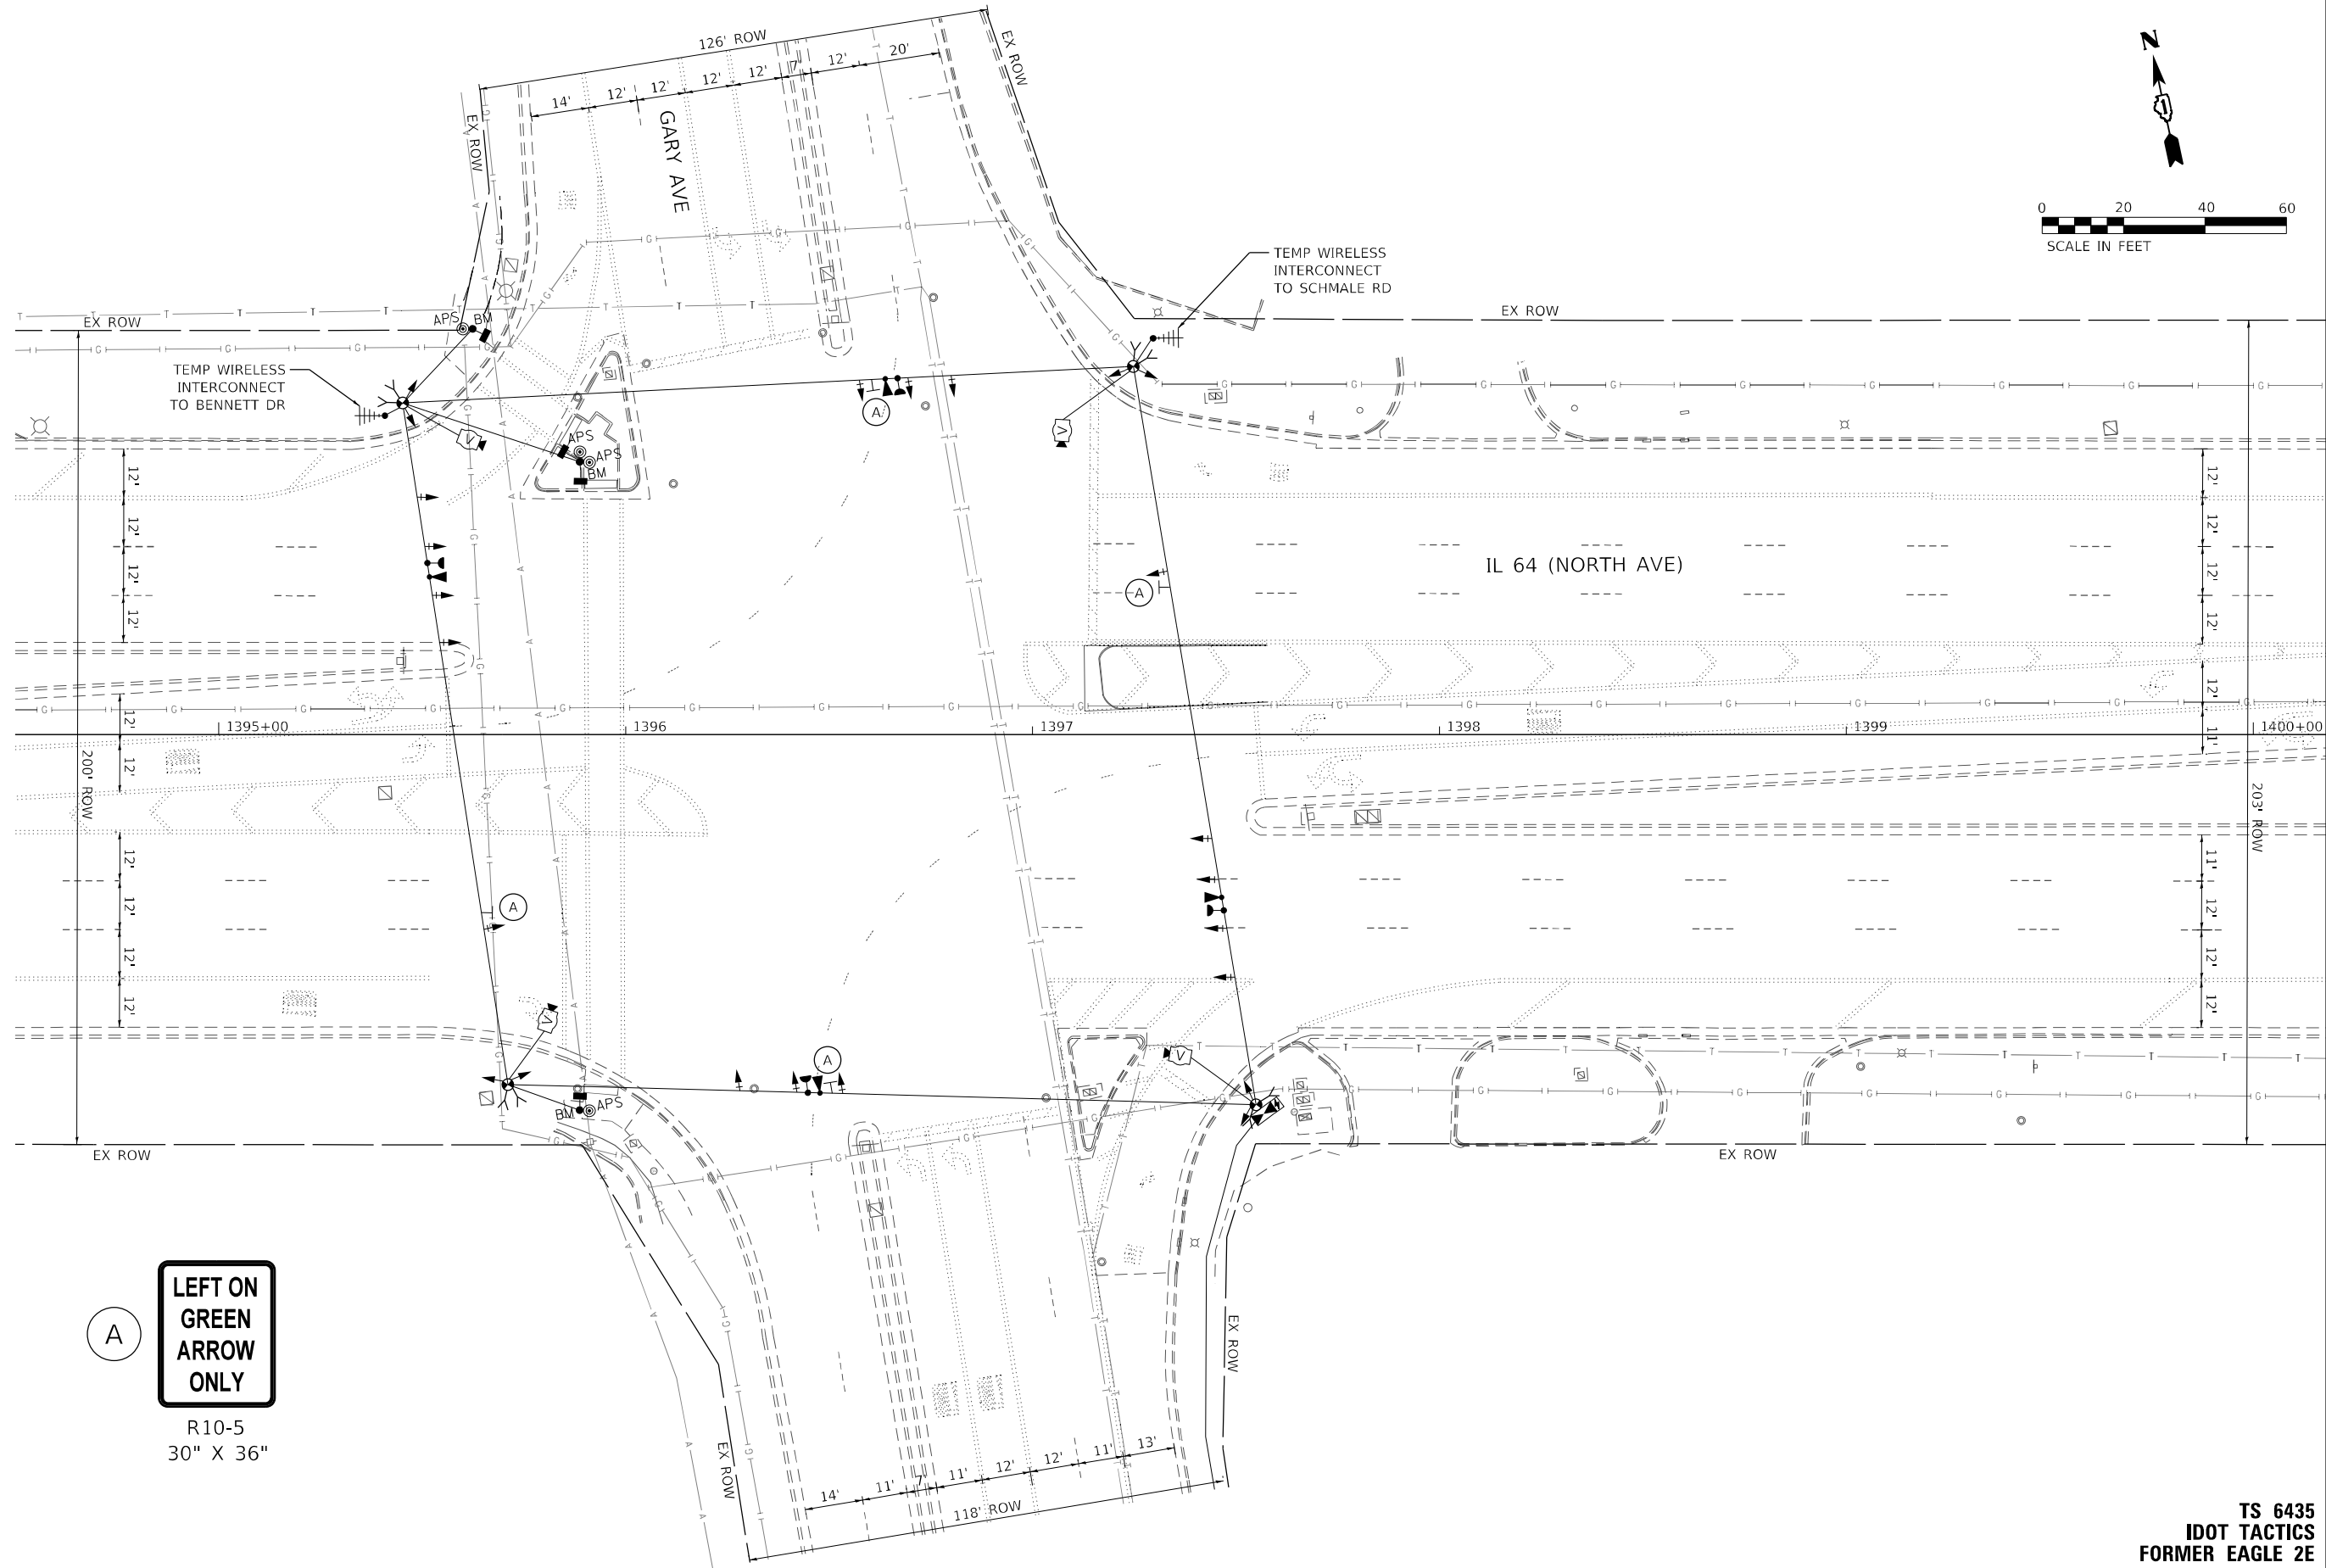

A
**LEFT ON
GREEN
ARROW
ONLY**
R10-5
30" X 36"

**TS 6435
IDOT TACTICS
FORMER EAGLE 2E**

Kimley»Horn

© 2021 KIMLEY-HORN AND ASSOCIATES, INC.
4001 WILSON ROAD, SUITE 600
WARREN, IL 60555
PHONE: (847) 455-4555
WWW.KIMLEY-HORN.COM

USER NAME =	DESIGNED -	REVISED -
	DRAWN -	REVISED -
PLOT SCALE =	CHECKED -	REVISED -
PLOT DATE =	DATE -	REVISED -


**STATE OF ILLINOIS
DEPARTMENT OF TRANSPORTATION**

**TRAFFIC SIGNAL EQUIPMENT TEMPORARY PLAN
IL 64 (NORTH AVE) AND GARY AVE**


SCALE: 1" = 20' SHEET OF SHEETS STA. TO STA.

F.A.P. RTE.	SECTION	COUNTY	TOTAL SHEETS	SHEET NO.
307	2020-263-SUR, SW&TS	DUPAGE	529	172
CONTRACT NO. 62N33				
ILLINOIS FED. AID PROJECT				

TEMPORARY CONTROLLER SEQUENCE

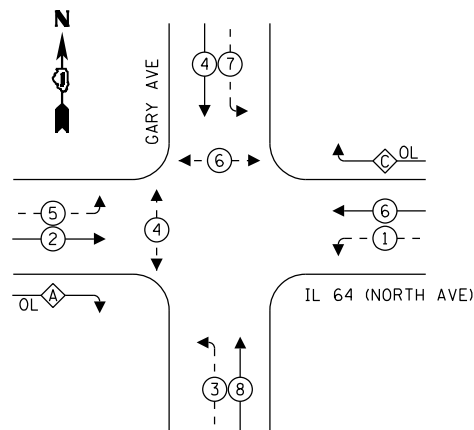


LEGEND:

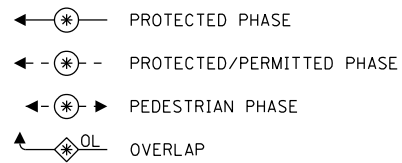

OVERLAP LETTER		PERMISSIVE PHASE		PROTECTED PHASE
A	=	2	+	3
C	=	6	+	7

TEMPORARY EMERGENCY VEHICLE PREEMPTION SEQUENCE

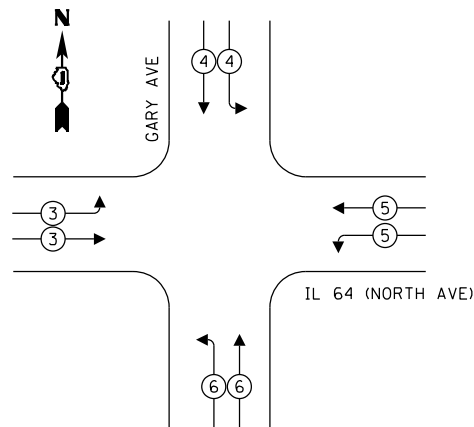

TRAFFIC SIGNAL ELECTRICAL SERVICE REQUIREMENTS

TYPE	QUANTITY	UNIT WATTAGE	TOTAL WATTAGE
SIGNAL HEAD 1 OR 3-SECTION	-	11	-
4-SECTION	-	14	-
5-SECTION	-	13	-
PROGRAMMABLE 3-SECTION	-	22	-
4-SECTION	-	32	-
5-SECTION	-	28	-
PEDESTRIAN SIGNAL	-	15	-
CONTROLLER	1	150	150
MASTER CONTROLLER	-	100	-
UPS	1	25	25
DETECTION VIDEO	-	20	-
BLANK-OUT SIGN	-	25	-
NETWORK SWITCH LAYER II OR III	1	35	35
CELLULAR MODEM	-	15	-
TOTAL UPS SIZING			210
UPS CHARGING	1	225	225
BATTERY HEATER MAT	1	180	180
CABINET HEATER	1	200	200
FLASHER	-	15	-
LED STREET NAME SIGN	-	120	-
LUMINAIRE	-	240	-
TOTAL SERVICE WIRE SIZING			815

NOTES

1. ONLY RED SIGNAL FACES SHALL HAVE A LENS COVER INSTALLED.

ENERGY COSTS TO:
ILLINOIS DEPARTMENT OF TRANSPORTATION
201 W CENTER CT
SCHAUMBURG, IL 60196


ENERGY SUPPLY: COMPANY: COMED
PHONE: (866) 639-3532
ACCOUNT NUMBER: 20051-18081

LEGEND:

L = LED LAMP MODULE REPLACEMENT
RL = RELOCATE
* = ROADWAY LIGHTING CABLE

CABLE PLAN

(NOT TO SCALE)

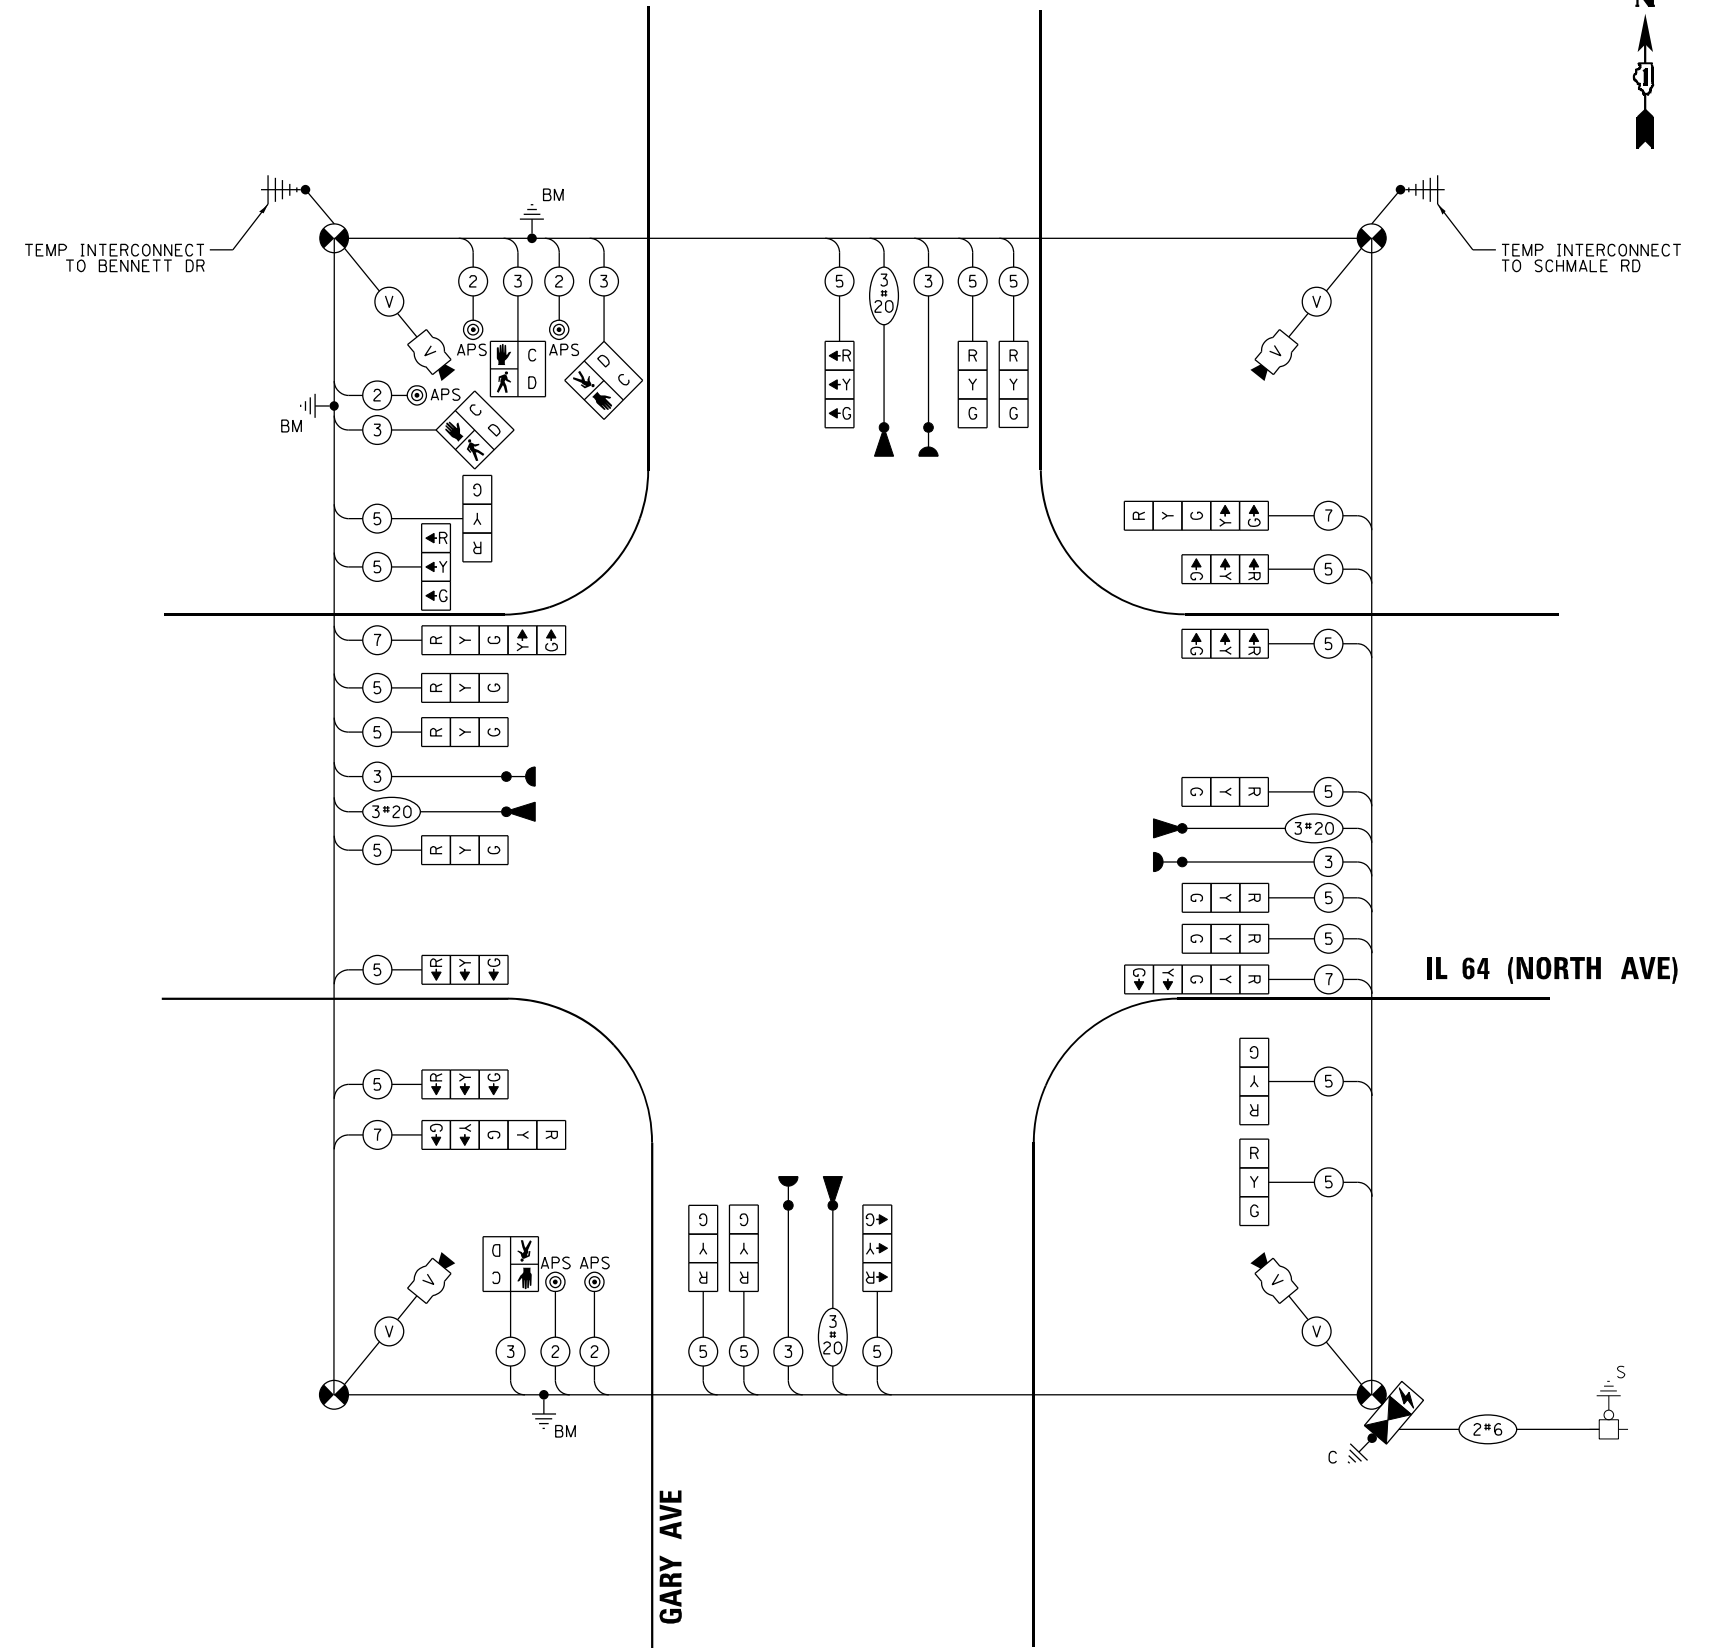

TS 6435
IDOT TACTICS
FORMER EAGLE 2E

F.A.P. RTE.	SECTION	COUNTY	TOTAL SHEETS	SHEET NO.
307	2020-263-SUR, SW&TS	DUPAGE	529	173
		CONTRACT NO. 62N33		
		ILLINOIS	FED. AID PROJECT	

**STATE OF ILLINOIS
DEPARTMENT OF TRANSPORTATION**

**TEMPORARY CABLE PLAN, PHASE DESIGNATION DIAGRAM, AND
EMERGENCY VEHICLE PREEMPTION SEQUENCE
IL 64 (NORTH AVE) AND GARY AVE**

SCALE: N.T.S.	SHEET	OF	SHEETS	STA.	TO STA.
---------------	-------	----	--------	------	---------

Kimley»»Horn

© 2023 KIMLEY-HORN AND ASSOCIATES, INC.
4201 WILFELD ROAD, SUITE 600
WARRENVILLE, IL 60555
PHONE: 630-487-5550
WWW.KIMLEY-HORN.COM

USER NAME	=	
PLOT SCALE	=	
PLOT DATE	=	

DESIGNED -
DRAWN -
CHECKED -
DATE -

REVISED	-
REVISED	-
REVISED	-
REVISED	-

MODEL: Default
FILE NAME: pw:\kh-pw\bentlev.com\kh-pw\01\Documents\01 Active Projects\MW-CHS-16899\100 - IL 64\Phase II\2 Design\CAD\Plan Sheets\Signal\Signal West Corridor Signal\ID10812 L-Sht-Ts-72 KHA.dgn

MODEL: Default
FILE: I:\Users\paul.bentley\Documents\01 Active Projects\IMW-CIS-680950\00 - IL 64 Phase II\2 Design\CAD\Plan_Sheets\Signal\West Corridor_Signal\01081714-IL-64-TS-73_KIM.dgn

NOTES

- ALL PROPOSED TRAFFIC SIGNAL CABLE SHALL BE ROUTED THROUGH THE PROPOSED CONDUIT.
- A SEPARATE LEAD-IN CABLE SHALL BE INSTALLED FOR THE DETECTOR LOOPS ON IL 64 (NORTH AVE).
- THERE SHALL BE A MINIMUM OF 4' SIDEWALK CLEARANCE IN FRONT/BEHIND OF THE TRAFFIC SIGNAL FOUNDATIONS TO BE ADA COMPLIANT.
- THE SIDEWALK CURBS ON ALL QUADRANTS SHALL BE CUT SO THAT THE POST AND MAST ARM FOUNDATIONS ARE FLUSH WITH THE EDGE OF THE SIDEWALK.
- ALL PUSH BUTTONS SHALL BE APS.
- THIS LOCATION HAS BEEN DESIGNED TO BE ADA COMPLIANT. ANY DEVIATION FROM THIS PLAN FOR THE POSTS THAT HAVE PEDESTRIAN EQUIPMENT WILL HAVE TO BE APPROVED BY THE ENGINEER TO ENSURE ADA COMPLIANCE.
- CONTRACTOR SHALL VERIFY THAT THE PLACEMENT OF THE PROPOSED SIGNAL EQUIPMENT ADJACENT TO EXISTING RAMPS MEET ADA REQUIREMENTS. THE ENGINEER SHALL APPROVE THE PROPOSED LOCATIONS OF THE SIGNAL EQUIPMENT BEFORE INSTALLATION.

KimleyHorn

© 2023 KIMLEY-HORN AND ASSOCIATES, INC.
4001 WILHELM D. ROAD, SUITE 600
WARREN, ILL. 60555
PHONE: (815) 474-4555
WWW.KIMLEY-HORN.COM

USER NAME =	DESIGNED -	REVISED -
	DRAWN -	REVISED -
PLOT SCALE =	CHECKED -	REVISED -
PLOT DATE =	DATE -	REVISED -

STATE OF ILLINOIS
DEPARTMENT OF TRANSPORTATION

TRAFFIC SIGNAL MODERNIZATION PLAN
IL 64 (NORTH AVE) AND GARY AVE




SCALE: 1" = 20' SHEET OF SHEETS STA. TO STA.

LEFT ON
GREEN
ARROW
ONLY

R10-5
30" X 36"

TS 6435
IDOT TACTICS
FORMER EAGLE 2E


F.A.P. RTE.	SECTION	COUNTY	TOTAL SHEETS	SHEET NO.
307	2020-263-SUR, SW&TS	DUPAGE	529	174
CONTRACT NO. 62N33				
ILLINOIS FED. AID PROJECT				

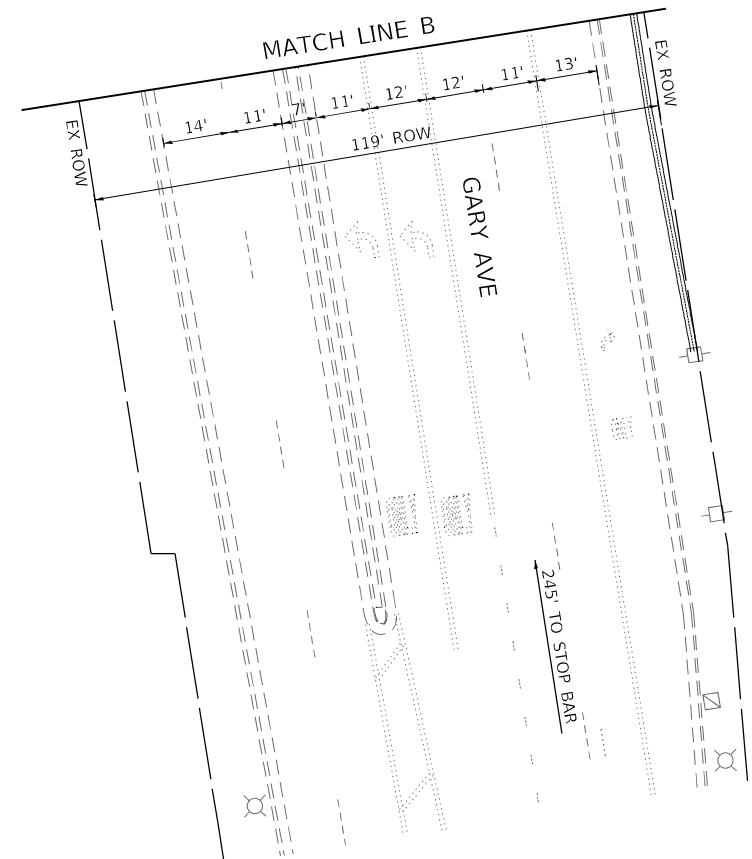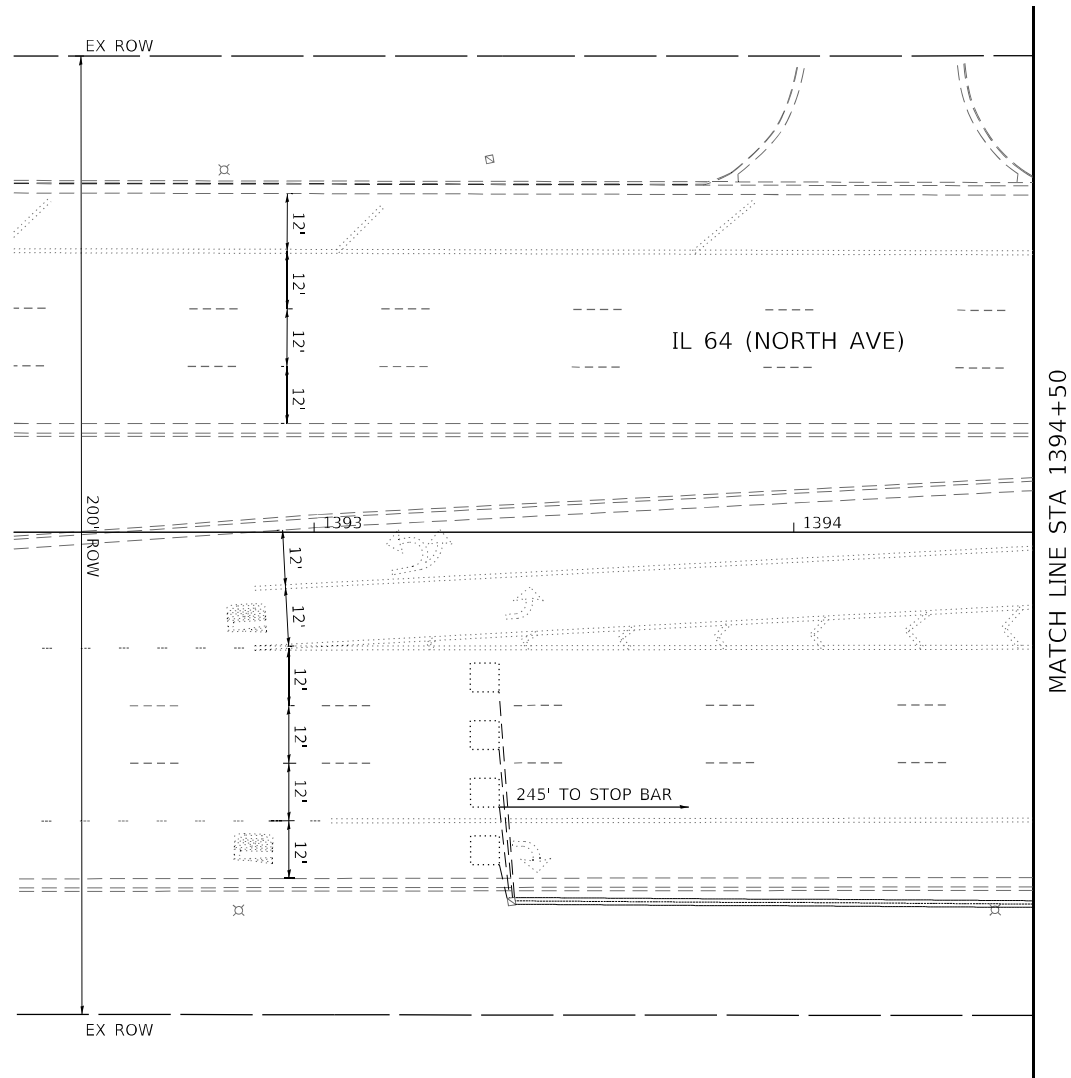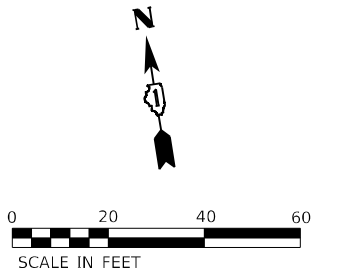


**TS 6435
IDOT TACTICS
FORMER EAGLE 2E**

 © 2023 KIMLEY-HORN AND ASSOCIATES, INC. 4201 WILSON D. HOWE, SUITE 600 WASHINGTON, D.C. 20005 PHONE: (202) 450-6500 WWW.KH-FIRM.COM	USER NAME =	DESIGNED -	REVISED -	STATE OF ILLINOIS DEPARTMENT OF TRANSPORTATION	TRAFFIC SIGNAL MODERNIZATION PLAN IL 64 (NORTH AVE) AND GARY AVE					F.A.P. RTE.	SECTION	COUNTY	TOTAL SHEETS	SHEET NO.
		DRAWN -	REVISED -							307	2020-263-SUR, SW&TS	DUPAGE	529	175
	PLOT SCALE =	CHECKED -	REVISED -		SCALE: 1" = 20' SHEET OF SHEETS STA. TO STA.					CONTRACT NO. 62N33				
	PLOT DATE =	DATE	REVISED -											

EXISTING AND PROPOSED
CONTROLLER SEQUENCE

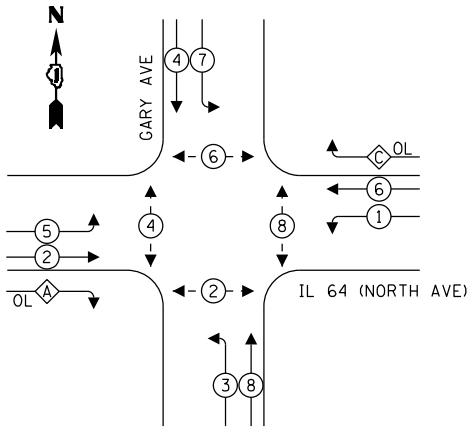


LEGEND:

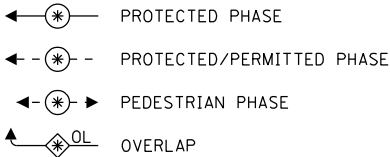

OVERLAP LETTER	PERMISSIVE PHASE	PROTECTED PHASE
A	= 2	+ 3
C	= 6	+ 7

EXISTING AND PROPOSED EMERGENCY
VEHICLE PREEMPTION SEQUENCE

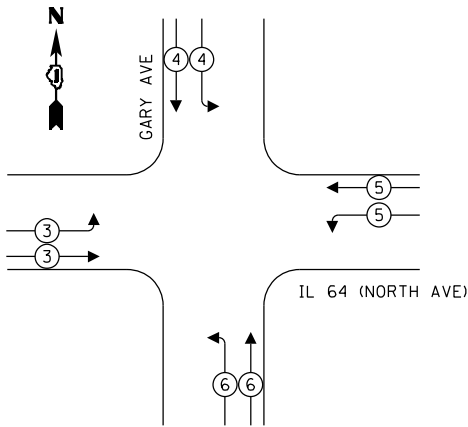

TRAFFIC SIGNAL
ELECTRICAL SERVICE REQUIREMENTS

TYPE	QUANTITY	UNIT WATTAGE	TOTAL WATTAGE
SIGNAL HEAD 1 OR 3-SECTION	-	11	-
4-SECTION	-	14	-
5-SECTION	-	13	-
PROGRAMMABLE 3-SECTION	-	22	-
4-SECTION	-	32	-
5-SECTION	-	28	-
PEDESTRIAN SIGNAL	-	15	-
CONTROLLER	1	150	150
MASTER CONTROLLER	-	100	-
UPS	1	25	25
DETECTION RADAR OR VIDEO	-	20	-
BLANK-OUT SIGN	-	25	-
NETWORK SWITCH II OR III	1	35	35
CELLULAR MODEM	-	15	-
TOTAL UPS SIZING			210
UPS CHARGING	1	225	225
BATTERY HEATER MAT	1	180	180
CABINET HEATER	1	200	200
FLASHER	-	15	-
LED STREET NAME SIGN	-	120	-
LUMINAIRE	-	240	-
TOTAL SERVICE WIRE SIZING			815


ENERGY COSTS TO:
ILLINOIS DEPARTMENT OF TRANSPORTATION
201 W CENTER CT
SCHAUMBURG, IL 60196

ENERGY SUPPLY: COMPANY: COMED
PHONE: (866) 639-3532
ACCOUNT NUMBER: 20051-18081

LEGEND:

L = LED LAMP MODULE REPLACEMENT
RL = RELOCATE
* = ROADWAY LIGHTING CABLE

CABLE PLAN
(NOT TO SCALE)

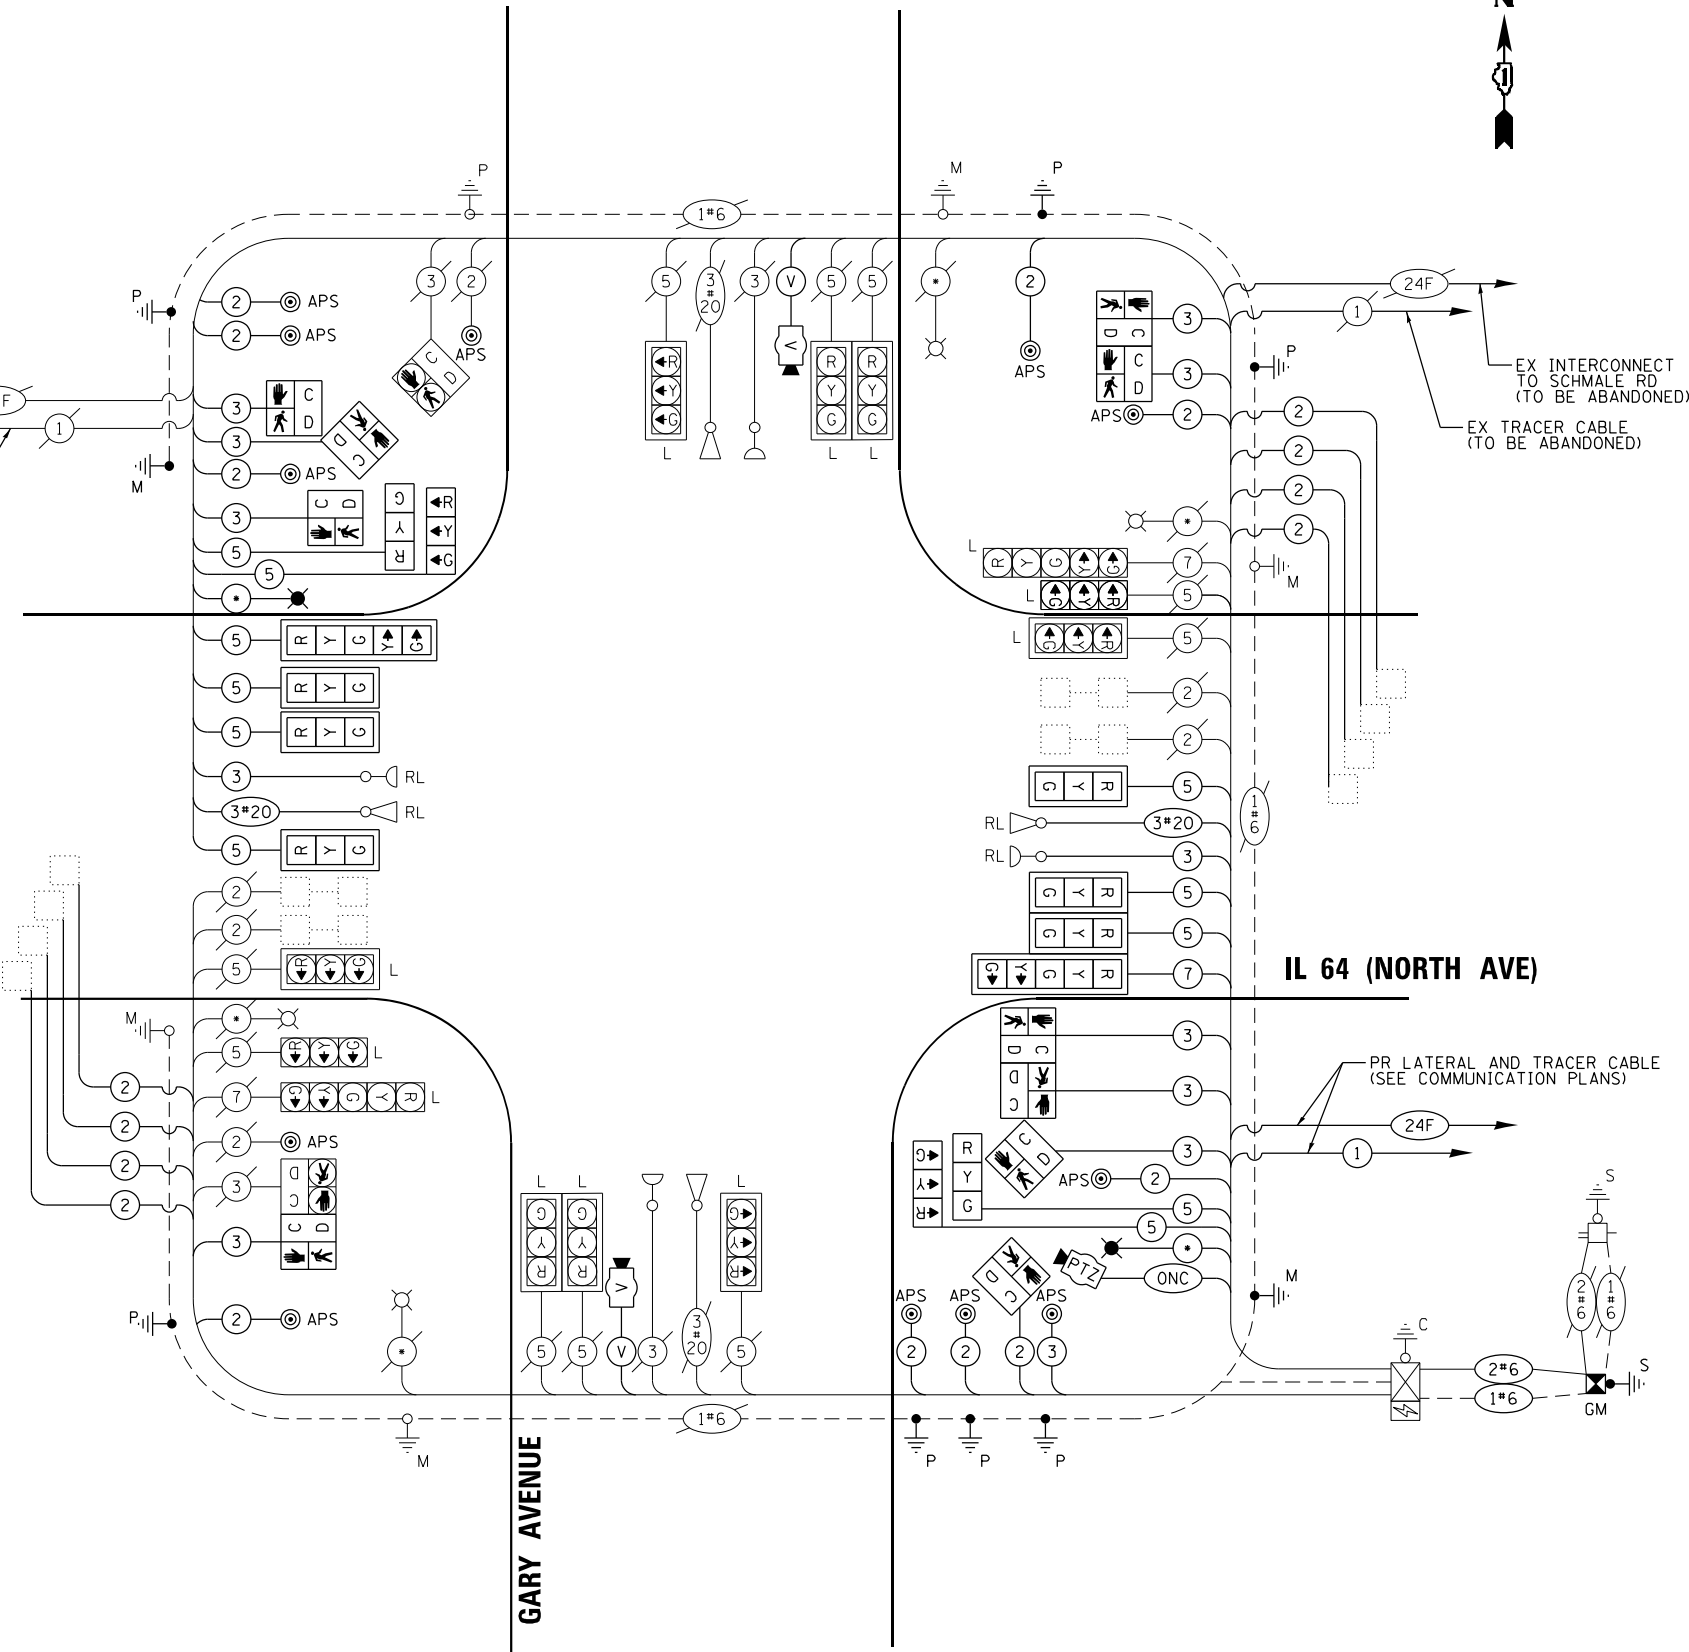

TS 6435
IDOT TACTICS
FORMER EAGLE 2E

KimleyHorn

© 2023 KIMLEY-HORN AND ASSOCIATES, INC.
4001 WILSON D. ROAD, SUITE 600
WARREN, IL 60555
PHONE: (847) 455-4555
WWW.KIMLEY-HORN.COM

USER NAME =	DESIGNED -	REVISED -
PLOT SCALE =	DRAWN -	REVISED -
PLOT DATE =	CHECKED -	REVISED -
	DATE -	REVISED -

STATE OF ILLINOIS
DEPARTMENT OF TRANSPORTATION

CABLE PLAN, PHASE DESIGNATION DIAGRAM, AND
EMERGENCY VEHICLE PREEMPTION SEQUENCE
IL 64 (NORTH AVE) AND GARY AVE

SCALE: N.T.S. SHEET OF SHEETS STA. TO STA.


F.A.P. RTE.	SECTION	COUNTY	TOTAL SHEETS	SHEET NO.
307	2020-263-SUR, SW&TS	DUPAGE	529	176
CONTRACT NO. 62N33				
ILLINOIS FED. AID PROJECT				

SIGN PANEL – TYPE 1 OR TYPE 2

ALL DIMENSIONS ARE IN INCHES UNLESS OTHERWISE NOTED



DESIGN SERIES	AREA (SQ FT)	SIGN PANEL TYPE	SHEETING TYPE	QTY. REQUIRED
D	12.5	2	ZZ	2

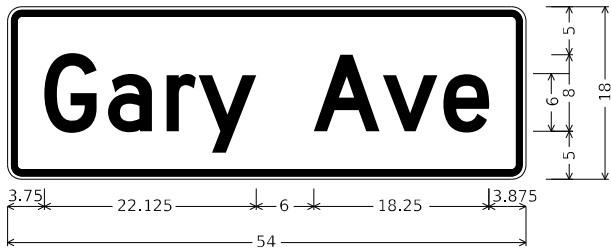

DESIGN SERIES	AREA (SQ FT)	SIGN PANEL TYPE	SHEETING TYPE	QTY. REQUIRED
D	6.75	1	ZZ	2

SCHEDULE OF QUANTITIES

ITEM DESCRIPTION	UNIT	QUANTITY
SIGN PANEL - TYPE 1	SQ FT	66.0
SIGN PANEL - TYPE 2	SQ FT	25
UNDERGROUND CONDUIT, GALVANIZED STEEL, 2" DIA.	FOOT	5
UNDERGROUND CONDUIT, GALVANIZED STEEL, 3" DIA.	FOOT	154
UNDERGROUND CONDUIT, GALVANIZED STEEL, 4" DIA.	FOOT	434
MAINTENANCE OF EXISTING TRAFFIC SIGNAL INSTALLATION	EACH	1
ELECTRIC CABLE IN CONDUIT, SIGNAL NO. 14 2C	FOOT	2460
ELECTRIC CABLE IN CONDUIT, SIGNAL NO. 14 3C	FOOT	3380
ELECTRIC CABLE IN CONDUIT, SIGNAL NO. 14 5C	FOOT	3210
ELECTRIC CABLE IN CONDUIT, SIGNAL NO. 14 7C	FOOT	642
ELECTRIC CABLE IN CONDUIT, LEAD-IN, NO. 14 1 PAIR	FOOT	3304
ELECTRIC CABLE IN CONDUIT, SERVICE, NO. 6 2 C	FOOT	44
ELECTRIC CABLE IN CONDUIT, EQUIPMENT GROUNDING CONDUCTOR, NO. 6 1C	FOOT	632
STEEL COMBINATION MAST ARM ASSEMBLY AND POLE 56 FT.	EACH	1
STEEL COMBINATION MAST ARM ASSEMBLY AND POLE 58 FT.	EACH	1
CONCRETE FOUNDATION, TYPE A	FOOT	4
CONCRETE FOUNDATION, TYPE E 42-INCH DIAMETER	FOOT	42
DRILL EXISTING HANDHOLE	EACH	15
SIGNAL HEAD, LED, 1-FACE, 3-SECTION, MAST-ARM MOUNTED	EACH	6
SIGNAL HEAD, LED, 1-FACE, 3-SECTION, BRACKET MOUNTED	EACH	4
SIGNAL HEAD, LED, 1-FACE, 5-SECTION, BRACKET MOUNTED	EACH	2
PEDESTRIAN SIGNAL HEAD, LED, 1-FACE, BRACKET MOUNTED WITH COUNTDOWN TIMER	EACH	10
TRAFFIC SIGNAL BACKPLATE, LOUVERED, FORMED PLASTIC	EACH	8
INDUCTIVE LOOP DETECTOR	EACH	8
TEMPORARY TRAFFIC SIGNAL INSTALLATION	EACH	1
* RELOCATE EXISTING EMERGENCY VEHICLE PRIORITY SYSTEM, DETECTOR UNIT	EACH	2
REMOVE EXISTING TRAFFIC SIGNAL EQUIPMENT	EACH	1
CLOSED CIRCUIT TELEVISION DOME CAMERA, HD	EACH	1
* EMERGENCY VEHICLE PRIORITY SYSTEM LINE SENSOR CABLE, NO. 20 3/C	FOOT	642
LED LAMP MODULE REPLACEMENT	EACH	40
OUTDOOR RATED NETWORK CABLE	FOOT	182
SERVICE INSTALLATION, GROUND MOUNTED, METERED	EACH	1
LAYER II (DATALINK) SWITCH	EACH	1
TERMINATE FIBER IN CABINET	EACH	12
PEDESTRIAN SIGNAL POST, 10 FT.	EACH	3
PEDESTRIAN SIGNAL POST, 5 FT.	EACH	4
TACTICS LICENSE EXPANSION	EACH	1
RELOCATE EXISTING LUMINAIRE	EACH	2
FULL-ACTUATED CONTROLLER IN EXISTING CABINET	EACH	1
REMOVE AND REPLACE BATTERIES FOR UNINTERRUPTABLE POWER SUPPLY, EXTENDED	EACH	1
FIBER OPTIC INTERCONNECT CENTER, 48 PORT	EACH	1
ACCESSIBLE PEDESTRIAN SIGNALS	EACH	12
CONCRETE FOUNDATION, TYPE A 12-INCH DIAMETER	FOOT	28
LED SIGNAL FACE, LENS COVER	EACH	24
VIDEO VEHICLE DETECTION SYSTEM, SINGLE APPROACH	EACH	2
TEMPORARY TRAFFIC SIGNAL TIMING	EACH	1

* - 100% COST TO THE VILLAGE OF CAROL STREAM

TS 6435
IDOT TACTICS
FORMER EAGLE 2E

MODEL: Default
FILE: Kimley-Horn\pvt-bentley.com\khp-gis\documents\01 Active Projects\MW\CHS-168959\100 - IL 64\Phase II\2 Design\CAD\Plan_Sheets\Sign\11aWest_Corridor_Signs\B01081714-rte-36_KHA.dgn

KimleyHorn

© 2023 KIMLEY-HORN AND ASSOCIATES, INC.
4001 HWY 10, SUITE 600
WARREN, IL 60555
PHONE: 847.447.4555
WWW.KIMLEY-HORN.COM

USER NAME =
PLOT SCALE =
PLOT DATE =

DESIGNED -
DRAWN -
CHECKED -
DATE -

REVISED -
REVISED -
REVISED -
REVISED -


STATE OF ILLINOIS
DEPARTMENT OF TRANSPORTATION

MAST ARM MOUNTED STREET NAME SIGNS AND
SCHEDULE OF QUANTITIES
IL 64 (NORTH AVE) AND GARY AVE

SCALE: N.T.S. SHEET OF SHEETS STA. TO STA.

F.A.P. RTE.	SECTION	COUNTY	TOTAL SHEETS	SHEET NO.
307	2020-263-SUR,SW&TS	DUPAGE	529	177
CONTRACT NO. 62N33				
ILLINOIS FED. AID PROJECT				

1. THE EXISTING TRAFFIC SIGNAL EQUIPMENT SHALL NOT BE REMOVED UNTIL THE PROPOSED TRAFFIC SIGNAL EQUIPMENT IS FULLY OPERATIONAL OR AS DIRECTED BY THE ENGINEER.
2. ALL EXISTING TRAFFIC SIGNAL CABLE NO LONGER REQUIRED SHALL BE REMOVED.

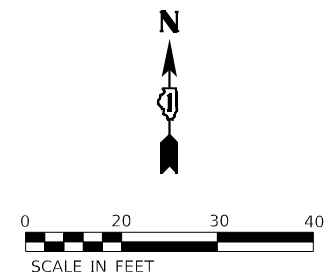

THE FOLLOWING EXISTING TRAFFIC SIGNAL EQUIPMENT SHALL BE REMOVED BY THE CONTRACTOR, SAFELY STORED AND RELOCATED TO THE PROPOSED MAST ARMS, POSTS, AND TRAFFIC SIGNAL CONTROLLER CABINET.


4	EACH	CONFIRMATION BEACON
4	EACH	LIGHT DETECTOR

THE FOLLOWING ITEMS SHALL BE REMOVED BY THE CONTRACTOR AND SHALL BE DISPOSED OF BY THEM OUTSIDE THE RIGHT-OF-WAY AT THEIR EXPENSE. THE SALVAGE VALUE OF THE REMOVED EQUIPMENT SHALL BE REFLECTED IN CONTRACT BID PRICE.

20	EACH	SIGNAL HEAD, 1-FACE, 3-SECTION
4	EACH	SIGNAL HEAD, 1-FACE, 5-SECTION
1	EACH	CONTROLLER (M40)
4	EACH	STREET NAME SIGN PANEL
14	EACH	TRAFFIC SIGNAL BACKPLATE
2	EACH	COMBINATION MAST ARM ASSEMBLY AND POLE
2	EACH	COMBINATION DUAL MAST ARM ASSEMBLY AND POLE
1	EACH	TRAFFIC SIGNAL POST

TS 6465
IDOT TACTICS
FORMER EAGLE 2E

1. ALL PROPOSED TRAFFIC SIGNAL CABLE SHALL BE ROUTED THROUGH THE PROPOSED CONDUIT.
2. A SEPARATE LEAD-IN CABLE SHALL BE INSTALLED FOR THE DETECTOR LOOPS ON IL 64 (NORTH AVE).
3. THERE SHALL BE A MINIMUM OF 4' SIDEWALK CLEARANCE IN FRONT/BEHIND OF THE TRAFFIC SIGNAL FOUNDATIONS TO BE ADA COMPLIANT.
4. THE SIDEWALK CURBS ON ALL QUADRANTS SHALL BE CUT SO THAT THE POST AND MAST ARM FOUNDATIONS ARE FLUSH WITH THE EDGE OF THE SIDEWALK.
5. ALL PUSH BUTTONS SHALL BE APS.
6. THIS LOCATION HAS BEEN DESIGNED TO BE ADA COMPLIANT. ANY DEVIATION FROM THIS PLAN FOR THE POSTS THAT HAVE PEDESTRIAN EQUIPMENT WILL HAVE TO BE APPROVED BY THE ENGINEER TO ENSURE ADA COMPLIANCE.
7. CONTRACTOR SHALL VERIFY THAT THE PLACEMENT OF THE PROPOSED SIGNAL EQUIPMENT ADJACENT TO EXISTING RAMPS MEET ADA REQUIREMENTS. THE ENGINEER SHALL APPROVE THE PROPOSED LOCATIONS OF THE SIGNAL EQUIPMENT BEFORE INSTALLATION.

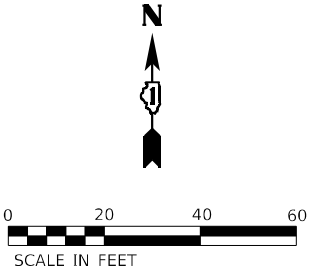

R10-5
30" X 36"
(8 REQUIRED)

© 2023 KIMLEY-HORN AND ASSOCIATES, INC.
4201 WINTERFIELD ROAD, SUITE 600
WARRENVILLE, IL 60555
PHONE: 630-487-5550
WWW.KIMLEY-HORN.COM


**STATE OF ILLINOIS
DEPARTMENT OF TRANSPORTATION**

SCALE: 1" = 20'	SHEET	OF	SHEETS	STA.	TO STA.
-----------------	-------	----	--------	------	---------


F.A.P. RTE.	SECTION	COUNTY	TOTAL SHEETS	SHEET NO.
307	2020-263-SUR,SW&TS	DUPAGE	529	180
		CONTRACT NO. 62N33		
ILLINOIS		FED. AID PROJECT		

MODEL: Default
FILE: 626162.dgn
Path: \\paw.bentley.com\hpc\d1\Documents\01 Active Projects\IMW-CUS-168959\100 - IL 64 Phase II\2 Design\CAD\Plan Sheets\Sign\West Corridor Sign\BID\0817-1-1-1-1-1-1-1.dgn

EXISTING
CONTROLLER SEQUENCE

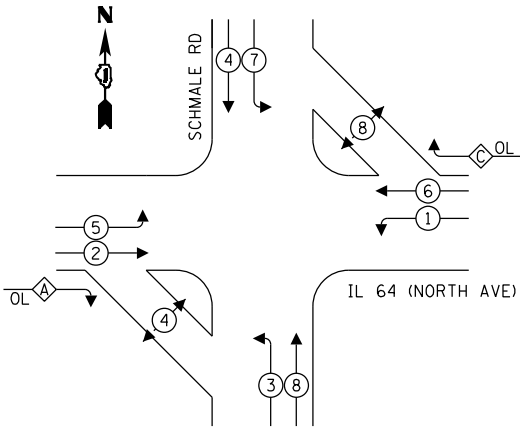


PROPOSED
CONTROLLER SEQUENCE

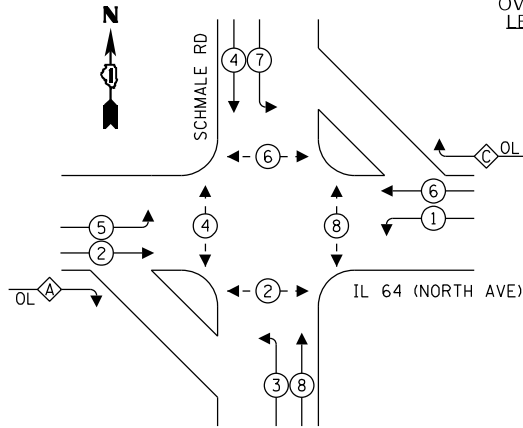

OVERLAP LETTER		PERMISSIVE PHASE		PROTECTED PHASE
A	=	2	+	3
C	=	6	+	7

EXISTING AND PROPOSED EMERGENCY
VEHICLE PREEMPTION SEQUENCE

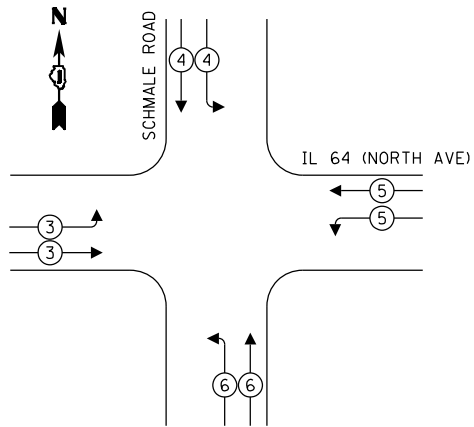

LEGEND:

- ← * → PROTECTED PHASE
- ← - * - → PROTECTED/PERMITTED PHASE
- ← * → PEDESTRIAN PHASE
- ← * OL → OVERLAP

TRAFFIC SIGNAL
ELECTRICAL SERVICE REQUIREMENTS

TYPE	QUANTITY	UNIT WATTAGE	TOTAL WATTAGE
SIGNAL HEAD 1 OR 3-SECTION	19	11	209
4-SECTION	-	14	-
5-SECTION	4	13	52
PROGRAMMABLE 3-SECTION	-	22	-
4-SECTION	-	32	-
5-SECTION	-	28	-
PEDESTRIAN SIGNAL CONTROLLER	12	15	180
MASTER CONTROLLER	1	150	150
UPS	-	100	-
DETECTION RADAR OR VIDEO	1	25	25
BLANK-OUT SIGN	2	20	40
NETWORK SWITCH II OR III	-	25	-
CELLULAR MODEM	1	35	35
PTZ	-	15	-
PTZ	1	75	75
TOTAL UPS SIZING			691
UPS CHARGING	1	225	225
BATTERY HEATER MAT	1	180	180
CABINET HEATER	1	200	200
FLASHER	-	15	-
LED STREET NAME SIGN	-	120	-
LUMINAIRE	4	240	960
TOTAL SERVICE WIRE SIZING			2256

ENERGY COSTS TO:
ILLINOIS DEPARTMENT OF TRANSPORTATION
201 W CENTER CT
SCHAUMBURG, IL 60196

ENERGY SUPPLY: COMPANY: COMED
PHONE: (866) 639-3532
ACCOUNT NUMBER: 00940-45191

LEGEND:

* = ROADWAY LIGHTING CABLE

CABLE PLAN

(NOT TO SCALE)

EX INTERCONNECT
TO GARY AVE (TO
BE ABANDONED)

EX TRACER CABLE
(TO BE ABANDONED)

IL 64 (NORTH AVE)

EX INTERCONNECT
TO PRESIDENT ST
(TO BE ABANDONED)

EX TRACER CABLE
(TO BE ABANDONED)

PR LATERAL
AND TRACER
CABLE (SEE
COMMUNICATIONS
PLANS)

TS 6465
IDOT TACTICS
FORMER EAGLE 2E

KimleyHorn

© 2023 KIMLEY-HORN AND ASSOCIATES, INC.
4001 WILLOW D. ROAD, SUITE 600
WARREN, IL 6. 60555
PHONE: (847) 455-4555
WWW.KIMLEY-HORN.COM

USER NAME	=	DESIGNED	-	REVISED	-
PLOT SCALE	=	DRAWN	-	REVISED	-
PLOT DATE	=	CHECKED	-	REVISED	-
		DATE	-	REVISED	-

STATE OF ILLINOIS
DEPARTMENT OF TRANSPORTATION


CABLE PLAN, PHASE DESIGNATION DIAGRAM, AND
EMERGENCY VEHICLE PREEMPTION SEQUENCE
IL 64 (NORTH AVE) AND SCHMALE RD

SCALE: N.T.S. SHEET OF SHEETS STA. TO STA.

F.A.P. RTE.	SECTION	COUNTY	TOTAL SHEETS	SHEET NO.
307	2020-263-SUR, SW&TS	DUPAGE	529	182
CONTRACT NO. 62N33				
ILLINOIS FED. AID PROJECT				

SIGN PANEL – TYPE 1 OR TYPE 2

ALL DIMENSIONS ARE IN INCHES UNLESS OTHERWISE NOTED

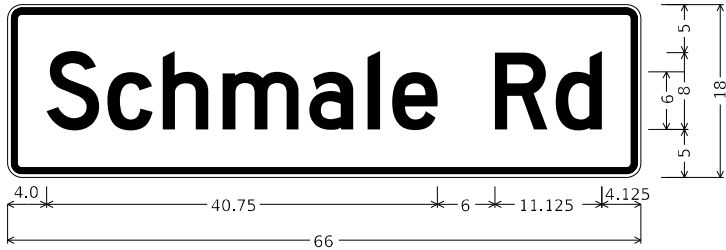

DESIGN SERIES	AREA (SQ FT)	SIGN PANEL TYPE	SHEETING TYPE	QTY. REQUIRED
D	8.25	1	ZZ	2



DESIGN SERIES	AREA (SQ FT)	SIGN PANEL TYPE	SHEETING TYPE	QTY. REQUIRED
D	12.5	2	ZZ	2

SCHEDULE OF QUANTITIES

ITEM DESCRIPTION	UNIT	QUANTITY
SIGN PANEL - TYPE 1	SQ FT	76.5
SIGN PANEL - TYPE 2	SQ FT	25
UNDERGROUND CONDUIT, GALVANIZED STEEL, 2" DIA.	FOOT	5
UNDERGROUND CONDUIT, GALVANIZED STEEL, 3" DIA.	FOOT	138
UNDERGROUND CONDUIT, GALVANIZED STEEL, 4" DIA.	FOOT	353
MAINTENANCE OF EXISTING TRAFFIC SIGNAL INSTALLATION	EACH	1
ELECTRIC CABLE IN CONDUIT, SIGNAL NO. 14 2C	FOOT	3001
ELECTRIC CABLE IN CONDUIT, SIGNAL NO. 14 3C	FOOT	4528
ELECTRIC CABLE IN CONDUIT, SIGNAL NO. 14 5C	FOOT	6158
ELECTRIC CABLE IN CONDUIT, SIGNAL NO. 14 7C	FOOT	902
ELECTRIC CABLE IN CONDUIT, LEAD-IN, NO. 14 1 PAIR	FOOT	1684
ELECTRIC CABLE IN CONDUIT, SERVICE, NO. 6 2 C	FOOT	38
ELECTRIC CABLE IN CONDUIT, EQUIPMENT GROUNDING CONDUCTOR, NO. 6 1C	FOOT	529
TRAFFIC SIGNAL POST, GALVANIZED STEEL 16 FT.	EACH	3
STEEL COMBINATION MAST ARM ASSEMBLY AND POLE 75 FT.	EACH	2
STEEL COMBINATION MAST ARM ASSEMBLY AND POLE WITH DUAL MAST ARMS, 28 FT. AND 50 FT.	EACH	2
CONCRETE FOUNDATION, TYPE A	FOOT	16
CONCRETE FOUNDATION, TYPE E 36-INCH DIAMETER	FOOT	32
CONCRETE FOUNDATION, TYPE E 42-INCH DIAMETER	FOOT	50
DRILL EXISTING HANDHOLE	EACH	13
SIGNAL HEAD, LED, 1-FACE, 3-SECTION, MAST-ARM MOUNTED	EACH	14
SIGNAL HEAD, LED, 1-FACE, 3-SECTION, BRACKET MOUNTED	EACH	2
SIGNAL HEAD, LED, 1-FACE, 5-SECTION, BRACKET MOUNTED	EACH	4
PEDESTRIAN SIGNAL HEAD, LED, 1-FACE, BRACKET MOUNTED WITH COUNTDOWN TIMER	EACH	12
TRAFFIC SIGNAL BACKPLATE, LOUVERED, FORMED PLASTIC	EACH	14
INDUCTIVE LOOP DETECTOR	EACH	10
* RELOCATE EXISTING EMERGENCY VEHICLE PRIORITY SYSTEM, DETECTOR UNIT	EACH	4
REMOVE EXISTING TRAFFIC SIGNAL EQUIPMENT	EACH	1
REMOVE EXISTING HANDHOLE	EACH	2
REMOVE EXISTING CONCRETE FOUNDATION	EACH	5
CLOSED CIRCUIT TELEVISION DOME CAMERA, HD	EACH	1
* EMERGENCY VEHICLE PRIORITY SYSTEM LINE SENSOR CABLE, NO. 20 3/C	FOOT	1332
OUTDOOR RATED NETWORK CABLE	FOOT	135
SERVICE INSTALLATION, GROUND MOUNTED, METERED	EACH	1
REMOTE CONTROLLED VIDEO SYSTEM	EACH	1
LAYER II (DATALINK) SWITCH	EACH	1
TERMINATE FIBER IN CABINET	EACH	12
PEDESTRIAN SIGNAL POST, 10 FT.	EACH	2
PEDESTRIAN SIGNAL POST, 5 FT.	EACH	1
TACTICS LICENSE EXPANSION	EACH	1
FULL-ACTUATED CONTROLLER IN EXISTING CABINET	EACH	1
REMOVE AND REPLACE BATTERIES FOR UNINTERRUPTABLE POWER SUPPLY, EXTENDED	EACH	1
FIBER OPTIC INTERCONNECT CENTER, 48 PORT	EACH	1
ACCESSIBLE PEDESTRIAN SIGNALS	EACH	12
CONCRETE FOUNDATION, TYPE A 12-INCH DIAMETER	FOOT	12
LED SIGNAL FACE, LENS COVER	EACH	25
VIDEO VEHICLE DETECTION SYSTEM, SINGLE APPROACH	EACH	2
CAMERA MOUNTING ASSEMBLY	EACH	1

* - 100% COST TO THE VILLAGE OF CAROL STREAM

TS 6465
IDOT TACTICS
FORMER EAGLE 2E

MODEL: Default
FILE: \\uslpc-prod\ut-pw-bentley.com\khp-gp-d\Documents\01 Active Projects\MW-CIS-68959\100 - IL 64\Phase II\2 Design\CAD\Plan_Sheets\Sign\IL West Corridor_Signs\BID10817-1-IL-Rts-52_K4A.dgn

Kimley»Horn

© 2021 KIMLEY-HORN AND ASSOCIATES, INC.
4001 HWY 10, SUITE 600
WARREN, IL 60555
PHONE: 847.447.4555
WWW.KIMLEY-HORN.COM

USER NAME =	DESIGNED -	REVISED -
	DRAWN -	REVISED -
PLOT SCALE =	CHECKED -	REVISED -
PLOT DATE =	DATE -	REVISED -


STATE OF ILLINOIS
DEPARTMENT OF TRANSPORTATION

MAST ARM MOUNTED STREET NAME SIGNS AND SCHEDULE OF QUANTITIES IL 64 (NORTH AVE) AND SCHMALE RD			
SCALE: N.T.S.	SHEET	OF	SHEETS
		STA.	TO STA.

F.A.P. RTE.	SECTION	COUNTY	TOTAL SHEETS	SHEET NO.
307	2020-263-SUR,SW&TS	DUPAGE	529	183
CONTRACT NO. 62N33				
		ILLINOIS	FED. AID PROJECT	

NOTES

1. THE EXISTING TRAFFIC SIGNAL EQUIPMENT SHALL NOT BE REMOVED UNTIL THE PROPOSED TRAFFIC SIGNAL EQUIPMENT IS FULLY OPERATIONAL OR AS DIRECTED BY THE ENGINEER.
2. ALL EXISTING TRAFFIC SIGNAL CABLE NO LONGER REQUIRED SHALL BE REMOVED.
3. THE REMOVAL OF THE EXISTING MASTER CONTROLLER SHALL INCLUDE DISCONNECTING THE EXISTING TELEPHONE SERVICE.

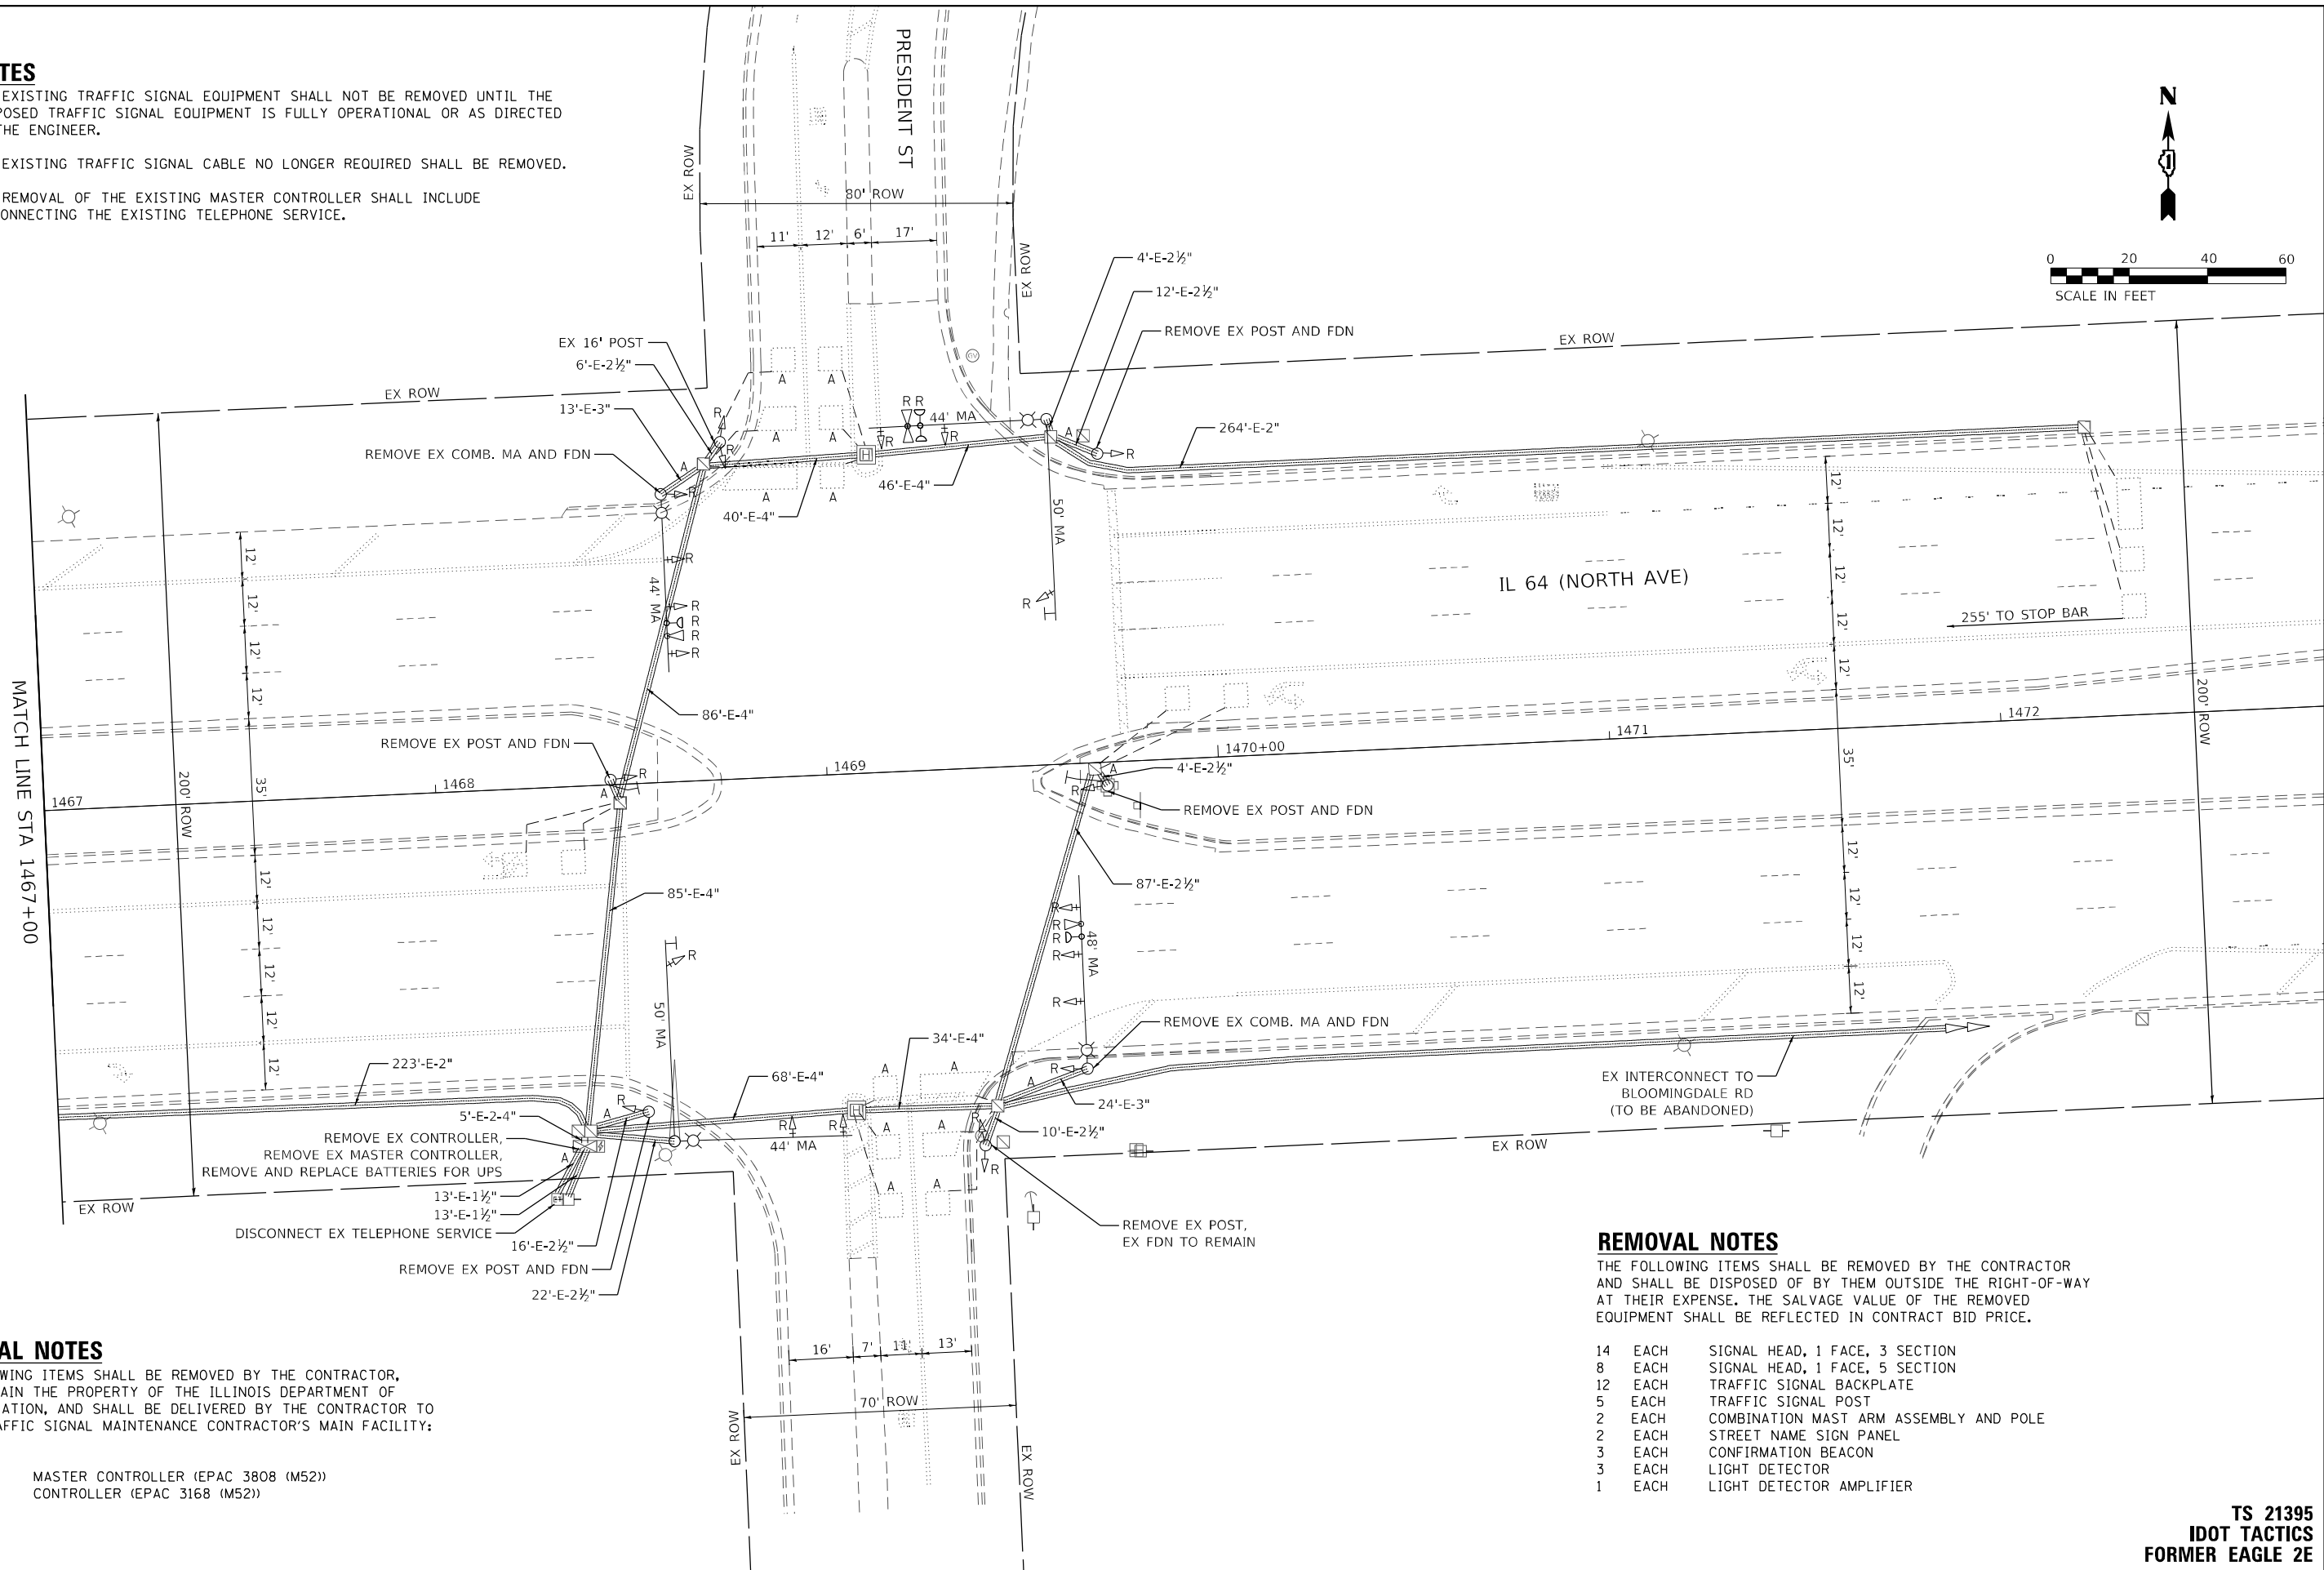

REMOVAL NOTES

THE FOLLOWING ITEMS SHALL BE REMOVED BY THE CONTRACTOR, SHALL REMAIN THE PROPERTY OF THE ILLINOIS DEPARTMENT OF TRANSPORTATION, AND SHALL BE DELIVERED BY THE CONTRACTOR TO IDOT'S TRAFFIC SIGNAL MAINTENANCE CONTRACTOR'S MAIN FACILITY:

- | | | |
|---|------|-------------------------------------|
| 1 | EACH | MASTER CONTROLLER (EPAC 3808 (M52)) |
| 1 | EACH | CONTROLLER (EPAC 3168 (M52)) |

REMOVAL NOTES

THE FOLLOWING ITEMS SHALL BE REMOVED BY THE CONTRACTOR AND SHALL BE DISPOSED OF BY THEM OUTSIDE THE RIGHT-OF-WAY AT THEIR EXPENSE. THE SALVAGE VALUE OF THE REMOVED EQUIPMENT SHALL BE REFLECTED IN CONTRACT BID PRICE.

- | | | |
|----|------|--|
| 14 | EACH | SIGNAL HEAD, 1 FACE, 3 SECTION |
| 8 | EACH | SIGNAL HEAD, 1 FACE, 5 SECTION |
| 12 | EACH | TRAFFIC SIGNAL BACKPLATE |
| 5 | EACH | TRAFFIC SIGNAL POST |
| 2 | EACH | COMBINATION MAST ARM ASSEMBLY AND POLE |
| 2 | EACH | STREET NAME SIGN PANEL |
| 3 | EACH | CONFIRMATION BEACON |
| 3 | EACH | LIGHT DETECTOR |
| 1 | EACH | LIGHT DETECTOR AMPLIFIER |

TS 21395
IDOT TACTICS
FORMER EAGLE 2E

KimleyHorn

© 2023 KIMLEY-HORN AND ASSOCIATES, INC.
4001 HWY 10 ROAD, SUITE 600
WARREN, IL 60555
PHONE: (847) 455-4555
WWW.KH-IL.COM



USER NAME	=	DESIGNED	-
		DRAWN	-
PLOT SCALE	=	CHECKED	-
PLOT DATE	=	DATE	-

STATE OF ILLINOIS
DEPARTMENT OF TRANSPORTATION

TRAFFIC SIGNAL EQUIPMENT REMOVAL PLAN
IL 64 (NORTH AVE) AND PRESIDENT ST

SCALE: 1" = 20' SHEET OF SHEETS STA. TO STA.

F.A.P. RTE.	SECTION	COUNTY	TOTAL SHEETS	SHEET NO.
307	2020-263-SUR,SW&TS	DUPAGE	529	184
CONTRACT NO. 62N33				
ILLINOIS FED. AID PROJECT				

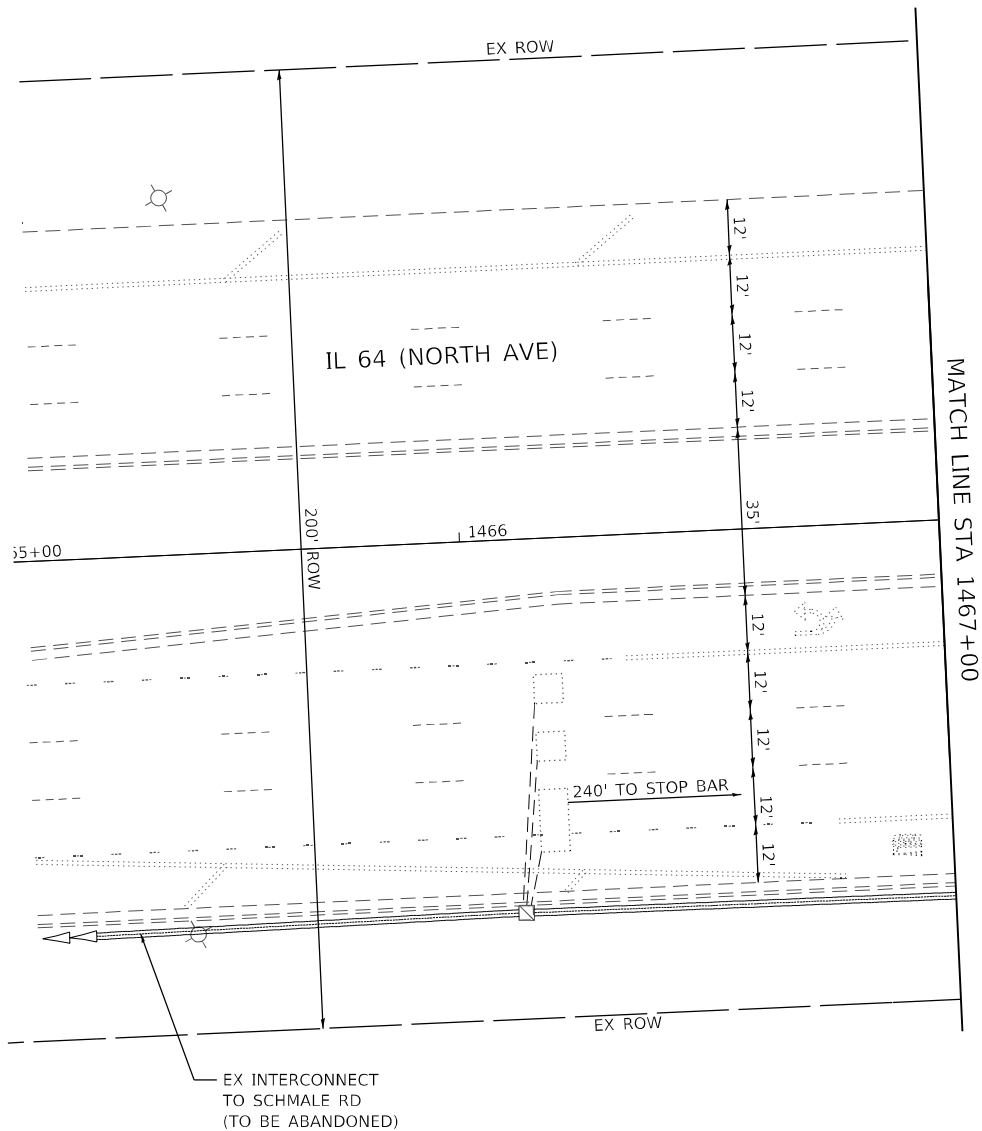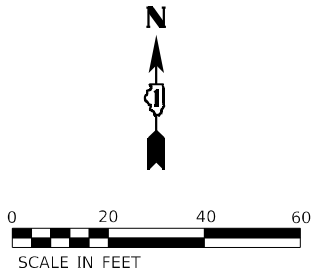

MODEL: Default
FILE NAME: p:\bentley\work\h-pw-d\11\Documents\01 Active Projects\IMW-CL-S-168950\00 - IL 64\Phase 1\2 Design\CAD\Plan Streets\Signal\West Corridor Signal\010817-14-IL-64-K4A.dgn





USER NAME =	DESIGNED -	REVISED -
	DRAWN -	REVISED -
PLOT SCALE =	CHECKED -	REVISED -
PLOT DATE =	DATE -	REVISED -

STATE OF ILLINOIS
DEPARTMENT OF TRANSPORTATION

TRAFFIC SIGNAL EQUIPMENT REMOVAL PLAN IL 64 (NORTH AVE) AND PRESIDENT ST			
SCALE: 1" = 20'	SHEET	OF	SHEETS
STA.		TO STA.	

F.A.P. RTE.	SECTION	COUNTY	TOTAL SHEETS	SHEET NO.
307	2020-263-SUR,SW&TS	DUPAGE	529	185
CONTRACT NO. 62N33				
ILLINOIS		FED. AID PROJECT		

TS 21395
IDOT TACTICS
FORMER EAGLE 2E

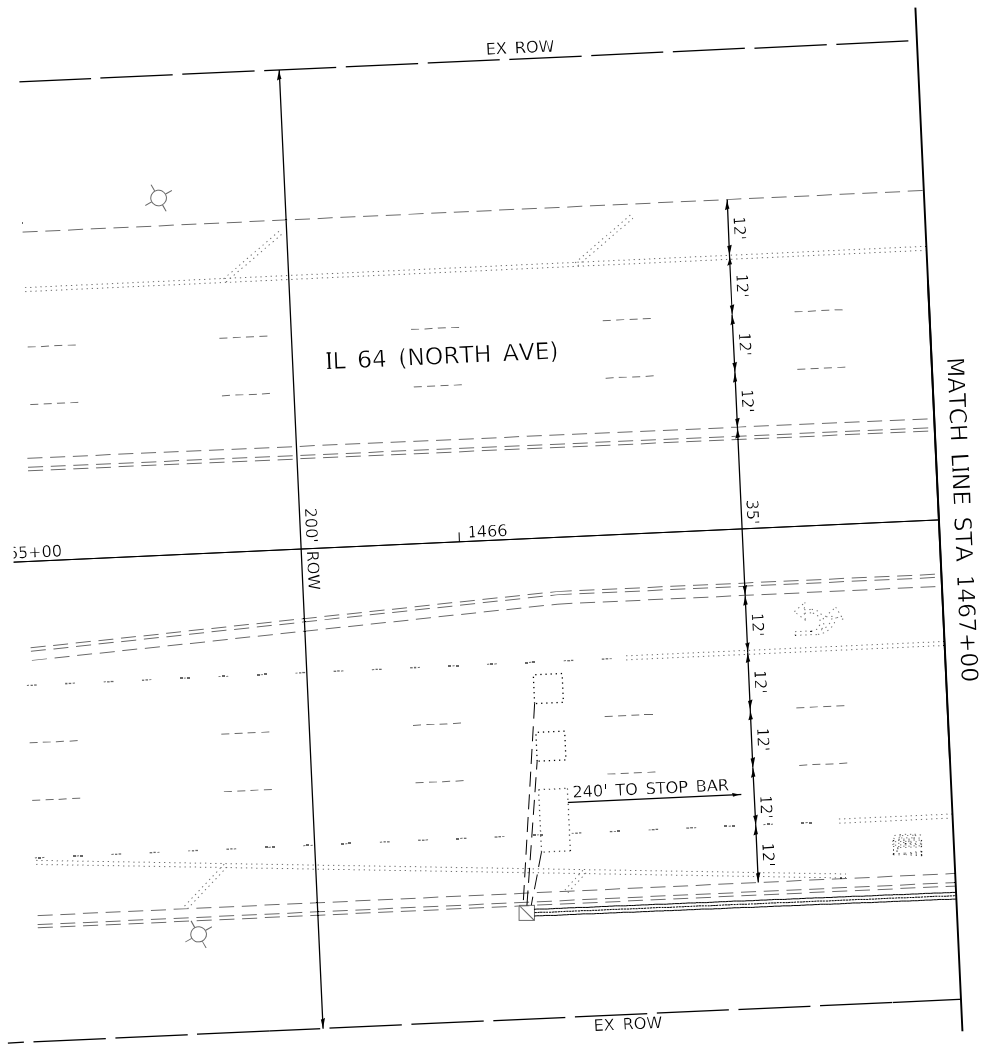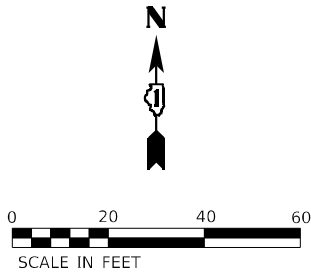

TS 21395
IDOT TACTICS
FORMER EAGLE 2E

MODEL: Default
FILE NAME: p:\work\pva\bartley.com\ts\ts-611\Documents\01 Active Projects\MW\CHS-168950\00 - IL 64\Phase II\2 Design\CAD\Plan Sheets\Signal\West Corridor Signal\01081714-IL-64-K4A.dgn



USER NAME =	DESIGNED -	REVISED -
	DRAWN -	REVISED -
PLOT SCALE =	CHECKED -	REVISED -
PLOT DATE =	DATE -	REVISED -


STATE OF ILLINOIS
DEPARTMENT OF TRANSPORTATION

TRAFFIC SIGNAL MODERNIZATION PLAN
IL 64 (NORTH AVE) AND PRESIDENT ST

SCALE: 1" = 20' SHEET OF SHEETS STA. TO STA.

F.A.P. RTE.	SECTION	COUNTY	TOTAL SHEETS	SHEET NO.
307	2020-263-SUR,SW&TS	DUPAGE	529	187
CONTRACT NO. 62N33				
		ILLINOIS	FED. AID PROJECT	

PROPOSED CONTROLLER SEQUENCE

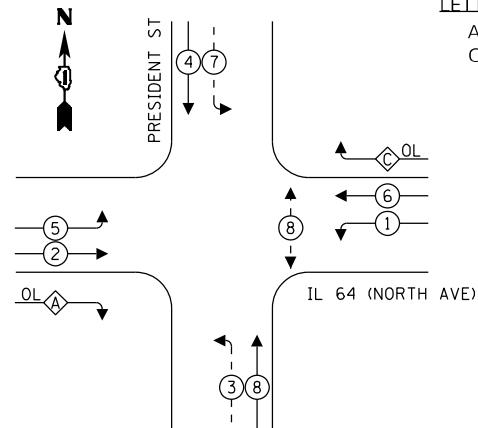

LEGEND:

-
- The diagram shows a four-way intersection. At the top, a north arrow points upwards, with a '1' in a circle next to it. The street name 'PRESIDENT ST' is written vertically along the top edge. The street name 'IL 64 (NORTH AVE)' is written horizontally along the right edge. The intersection is divided into four quadrants by a vertical line and a horizontal line. In the top-left quadrant, there is a circle with the number '5' and a downward-pointing arrow. In the top-right quadrant, there are two circles, each with the number '4', and two leftward-pointing arrows. In the bottom-left quadrant, there are two circles, each with the number '3', and two rightward-pointing arrows. In the bottom-right quadrant, there is a circle with the number '5' and an upward-pointing arrow.

LEGEND:

CABLE PLAN
(NOT TO SCALE)


F.A.P. RTE.	SECTION	COUNTY	TOTAL SHEETS	SHEET NO.
307	2020-263-SUR,SW&TS	DUPAGE	529	188
		CONTRACT NO. 62N33		
		ILLINOIS FED. AID PROJECT		

SIGN PANEL – TYPE 1 OR TYPE 2

ALL DIMENSIONS ARE IN INCHES UNLESS OTHERWISE NOTED



DESIGN SERIES	AREA (SQ FT)	SIGN PANEL TYPE	SHEETING TYPE	QTY. REQUIRED
D	12.5	2	ZZ	2

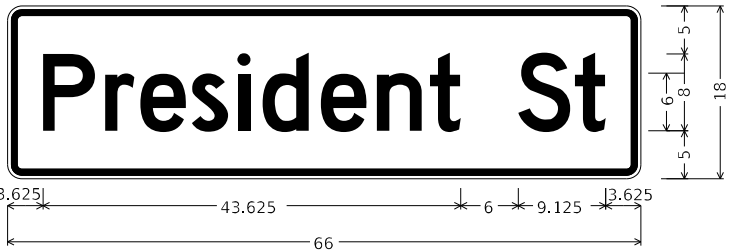

DESIGN SERIES	AREA (SQ FT)	SIGN PANEL TYPE	SHEETING TYPE	QTY. REQUIRED
D	8.25	1	ZZ	2

SCHEDULE OF QUANTITIES

ITEM DESCRIPTION	UNIT	QUANTITY
SIGN PANEL - TYPE 1	SQ FT	46.5
SIGN PANEL - TYPE 2	SQ FT	25.0
UNDERGROUND CONDUIT, GALVANIZED STEEL, 2" DIA.	FOOT	36
UNDERGROUND CONDUIT, GALVANIZED STEEL, 4" DIA.	FOOT	46
MAINTENANCE OF EXISTING TRAFFIC SIGNAL INSTALLATION	EACH	1
ELECTRIC CABLE IN CONDUIT, SIGNAL NO. 14 2C	FOOT	509
ELECTRIC CABLE IN CONDUIT, SIGNAL NO. 14 3C	FOOT	509
ELECTRIC CABLE IN CONDUIT, SIGNAL NO. 14 5C	FOOT	2870
ELECTRIC CABLE IN CONDUIT, SIGNAL NO. 14 7C	FOOT	1052
ELECTRIC CABLE IN CONDUIT, LEAD-IN, NO. 14 1 PAIR	FOOT	1506
ELECTRIC CABLE IN CONDUIT, SERVICE, NO. 6 2 C	FOOT	24
ELECTRIC CABLE IN CONDUIT, EQUIPMENT GROUNDING CONDUCTOR, NO. 6 1C	FOOT	70
TRAFFIC SIGNAL POST, GALVANIZED STEEL 16 FT.	EACH	1
STEEL COMBINATION MAST ARM ASSEMBLY AND POLE 64 FT.	EACH	2
CONCRETE FOUNDATION, TYPE A	FOOT	4
CONCRETE FOUNDATION, TYPE E 42-INCH DIAMETER	FOOT	42
DRILL EXISTING HANDHOLE	EACH	4
SIGNAL HEAD, LED, 1-FACE, 3-SECTION, MAST-ARM MOUNTED	EACH	12
SIGNAL HEAD, LED, 1-FACE, 3-SECTION, BRACKET MOUNTED	EACH	2
SIGNAL HEAD, LED, 1-FACE, 5-SECTION, BRACKET MOUNTED	EACH	2
SIGNAL HEAD, LED, 1-FACE, 5-SECTION, MAST-ARM MOUNTED	EACH	6
PEDESTRIAN SIGNAL HEAD, LED, 1-FACE, BRACKET MOUNTED WITH COUNTDOWN TIMER	EACH	2
TRAFFIC SIGNAL BACKPLATE, LOUVERED, FORMED PLASTIC	EACH	18
INDUCTIVE LOOP DETECTOR	EACH	4
* LIGHT DETECTOR	EACH	4
* LIGHT DETECTOR AMPLIFIER	EACH	1
REMOVE EXISTING TRAFFIC SIGNAL EQUIPMENT	EACH	1
REMOVE EXISTING CONCRETE FOUNDATION	EACH	5
* EMERGENCY VEHICLE PRIORITY SYSTEM LINE SENSOR CABLE, NO. 20 3/C	FOOT	574
SERVICE INSTALLATION, GROUND MOUNTED, METERED	EACH	1
LAYER II (DATALINK) SWITCH	EACH	1
TERMINATE FIBER IN CABINET	EACH	12
PEDESTRIAN SIGNAL POST, 10 FT.	EACH	2
TACTICS LICENSE EXPANSION	EACH	1
FULL-ACTUATED CONTROLLER IN EXISTING CABINET	EACH	1
REMOVE AND REPLACE BATTERIES FOR UNINTERRUPTABLE POWER SUPPLY, EXTENDED	EACH	1
FIBER OPTIC INTERCONNECT CENTER, 48 PORT	EACH	1
ACCESSIBLE PEDESTRIAN SIGNALS	EACH	2
CONCRETE FOUNDATION, TYPE A 12-INCH DIAMETER	FOOT	8
LED SIGNAL FACE, LENS COVER	EACH	22
VIDEO VEHICLE DETECTION SYSTEM, SINGLE APPROACH	EACH	2

* - 100% COST TO THE VILLAGE OF GLENDALE HEIGHTS

TS 21395
IDOT TACTICS
FORMER EAGLE 2E

MODEL: Default
FILE: \\miller-prod-bentley.com\khp\p4\1\Documents\01 Active Projects\MW-C\I-S-16895\000 - IL 64\Phase 1\12 Design\CAD\Plan_Sheets\Sign\1\West_Corridor_Sign\BID\08\12-1-Int-rs-38_KHA.dgn

KimleyHorn

© 2023 KIMLEY-HORN AND ASSOCIATES, INC.
4001 HWY 10, SUITE 600
WARREN, IL 60555
PHONE: 847.447.4555
WWW.KIMLEY-HORN.COM

USER NAME =	DESIGNED -	REVISED -
	DRAWN -	REVISED -
PLOT SCALE =	CHECKED -	REVISED -
PLOT DATE =	DATE -	REVISED -

STATE OF ILLINOIS
DEPARTMENT OF TRANSPORTATION

MAST ARM MOUNTED STREET NAME SIGNS AND SCHEDULE OF QUANTITIES IL 64 (NORTH AVE) AND PRESIDENT ST			
SCALE: N.T.S.	SHEET	OF	SHEETS
	STA.	TO	STA.

F.A.P. RTE.	SECTION	COUNTY	TOTAL SHEETS	SHEET NO.
307	2020-263-SUR,SW&TS	DUPAGE	529	189
CONTRACT NO. 62N33				
ILLINOIS FED. AID PROJECT				

REMOVAL NOTES


THE FOLLOWING ITEMS SHALL BE REMOVED BY THE CONTRACTOR AND SHALL BE DISPOSED OF BY THEM OUTSIDE THE RIGHT-OF-WAY AT THEIR EXPENSE. THE SALVAGE VALUE OF THE REMOVED EQUIPMENT SHALL BE REFLECTED IN CONTRACT BID PRICE.

- 20 EACH 3-SECTION SIGNAL HEAD
- 4 EACH 5-SECTION SIGNAL HEAD
- 1 EACH CONTROLLER (M52)
- 4 EACH STREET NAME SIGN PANEL
- 14 EACH TRAFFIC SIGNAL BACKPLATE
- 2 EACH COMBINATION DUAL MAST ARM ASSEMBLY AND POLE
- 2 EACH COMBINATION MAST ARM ASSEMBLY AND POLE

RELOCATION NOTES

THE FOLLOWING EXISTING TRAFFIC SIGNAL EQUIPMENT SHALL BE REMOVED BY THE CONTRACTOR, SAFELY STORED AND RELOCATED TO THE PROPOSED MAST ARMS, POSTS, AND TRAFFIC SIGNAL CONTROLLER CABINET.

- 4 EACH CONFIRMATION BEACON
- 4 EACH LIGHT DETECTOR

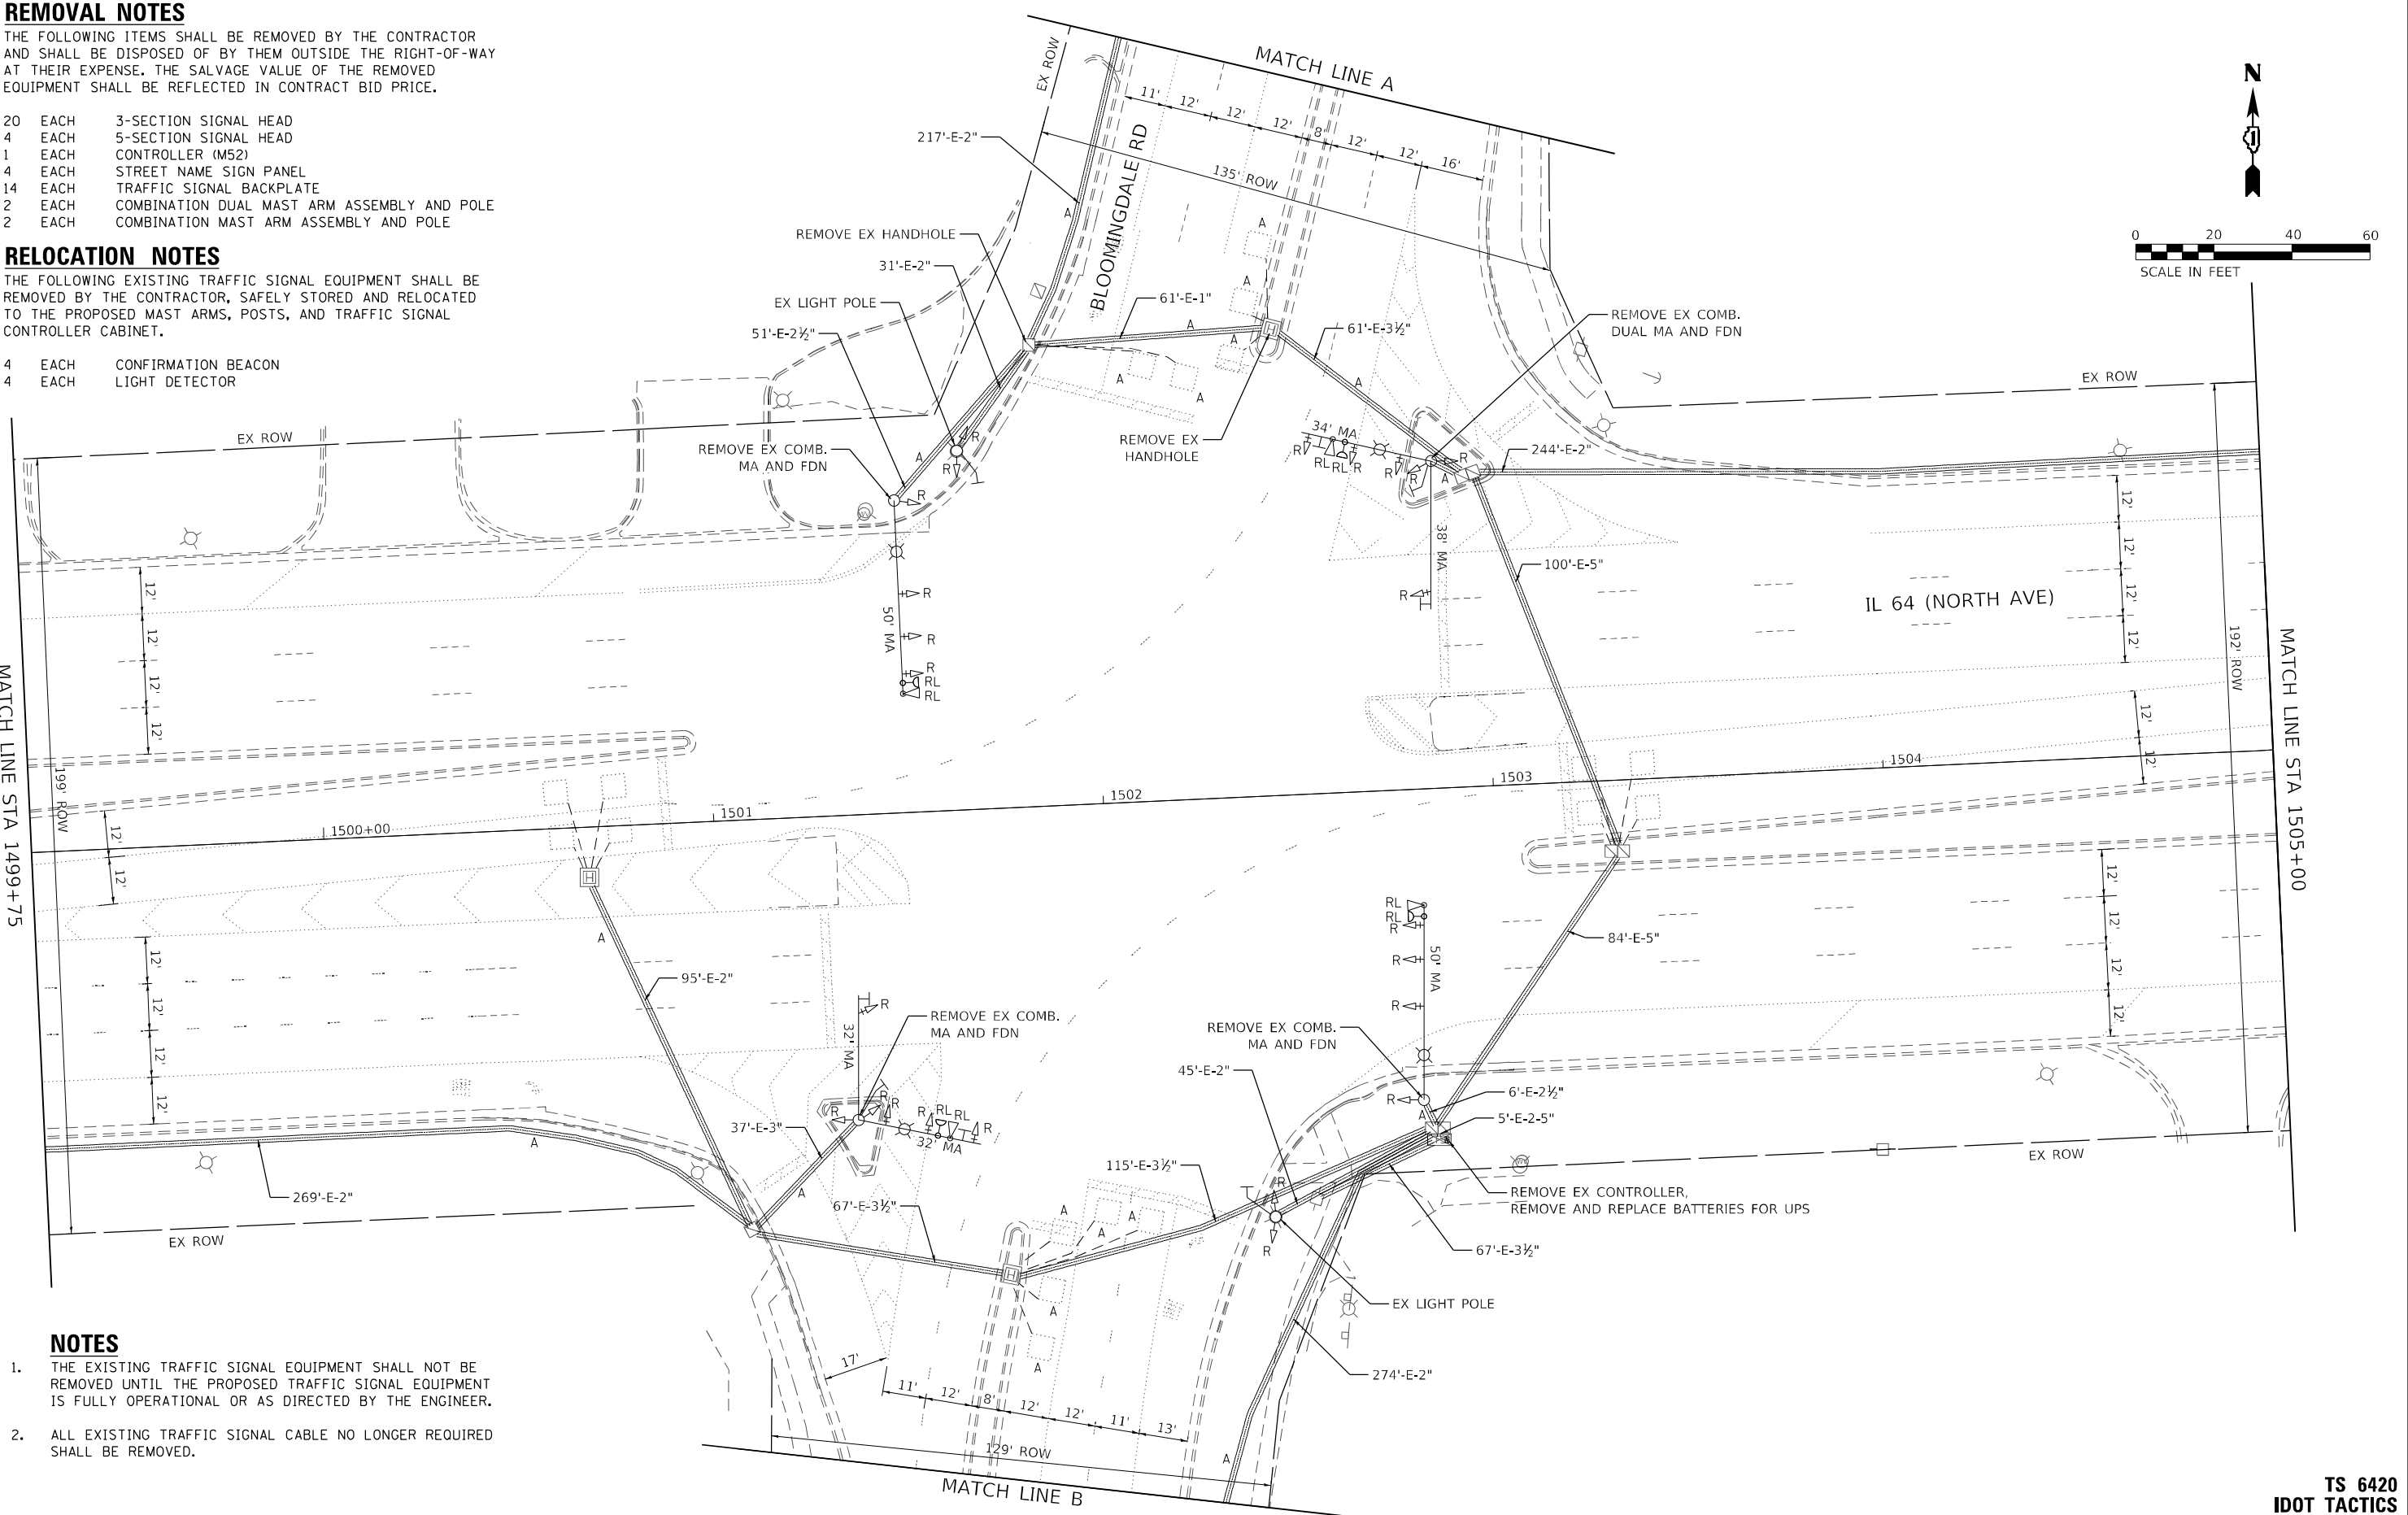

NOTES

- 1. THE EXISTING TRAFFIC SIGNAL EQUIPMENT SHALL NOT BE REMOVED UNTIL THE PROPOSED TRAFFIC SIGNAL EQUIPMENT IS FULLY OPERATIONAL OR AS DIRECTED BY THE ENGINEER.
- 2. ALL EXISTING TRAFFIC SIGNAL CABLE NO LONGER REQUIRED SHALL BE REMOVED.

MODEL: Default
FILE: I:\Users\paul.bentley\Documents\01 Active Projects\IMW-CHS-680950\00 - IL 64\Phase II\2 Design\CAD\Plan_Signals\West Corridor_Signals\010817-1-IL-64-99_KIM.dgn

KimleyHorn

© 2023 KIMLEY-HORN AND ASSOCIATES, INC.
4001 HWY 10, SUITE 600
WARREN, IL 60555
PHONE: (847) 455-4555
WWW.KIMLEY-HORN.COM

USER NAME =	DESIGNED -	REVISED -
	DRAWN -	REVISED -
PLOT SCALE =	CHECKED -	REVISED -
PLOT DATE =	DATE -	REVISED -

STATE OF ILLINOIS
DEPARTMENT OF TRANSPORTATION

TRAFFIC SIGNAL EQUIPMENT REMOVAL PLAN
IL 64 (NORTH AVE) AND BLOOMINGDALE RD

SCALE: 1" = 20' SHEET OF SHEETS STA. TO STA.

F.A.P. RTE.	SECTION	COUNTY	TOTAL SHEETS	SHEET NO.
307	2020-263-SUR, SW&TS	DUPAGE	529	190
CONTRACT NO. 62N33				
ILLINOIS FED. AID PROJECT				

TS 6420
IDOT TACTICS
FORMER EAGLE 2E

MODEL: Default
FILE NAME: p:\sub-pw\bartley.com\k-h-pw-d\1\Documents\01 Active Projects\IMW\CHS-168959\100 - IL 64\Phase II\2 Design\CAD\Plan Sheets\Signal\West Corridor Signal\BID\081714\ts-90_K4A.dgn




Kimley»Horn
© 2021 KIMLEY-HORN AND ASSOCIATES, INC.
4001 WILHELM ROAD, SUITE 600
WARREN, ILL. 60555
PHONE: 815.477.4555
WWW.KIMLEY-HORN.COM

USER NAME =	DESIGNED -	REVISED -
	DRAWN -	REVISED -
PLOT SCALE =	CHECKED -	REVISED -
PLOT DATE =	DATE -	REVISED -

STATE OF ILLINOIS
DEPARTMENT OF TRANSPORTATION

TRAFFIC SIGNAL EQUIPMENT REMOVAL PLAN IL 64 (NORTH AVE) AND BLOOMINGDALE RD			
SCALE: 1" = 20'	SHEET	OF	SHEETS
	STA.	TO	STA.


F.A.P. RTE.	SECTION	COUNTY	TOTAL SHEETS	SHEET NO.
307	2020-263-SUR,SW&TS	DUPAGE	529	191
CONTRACT NO. 62N33				
ILLINOIS		FED. AID PROJECT		

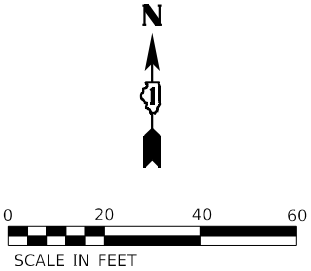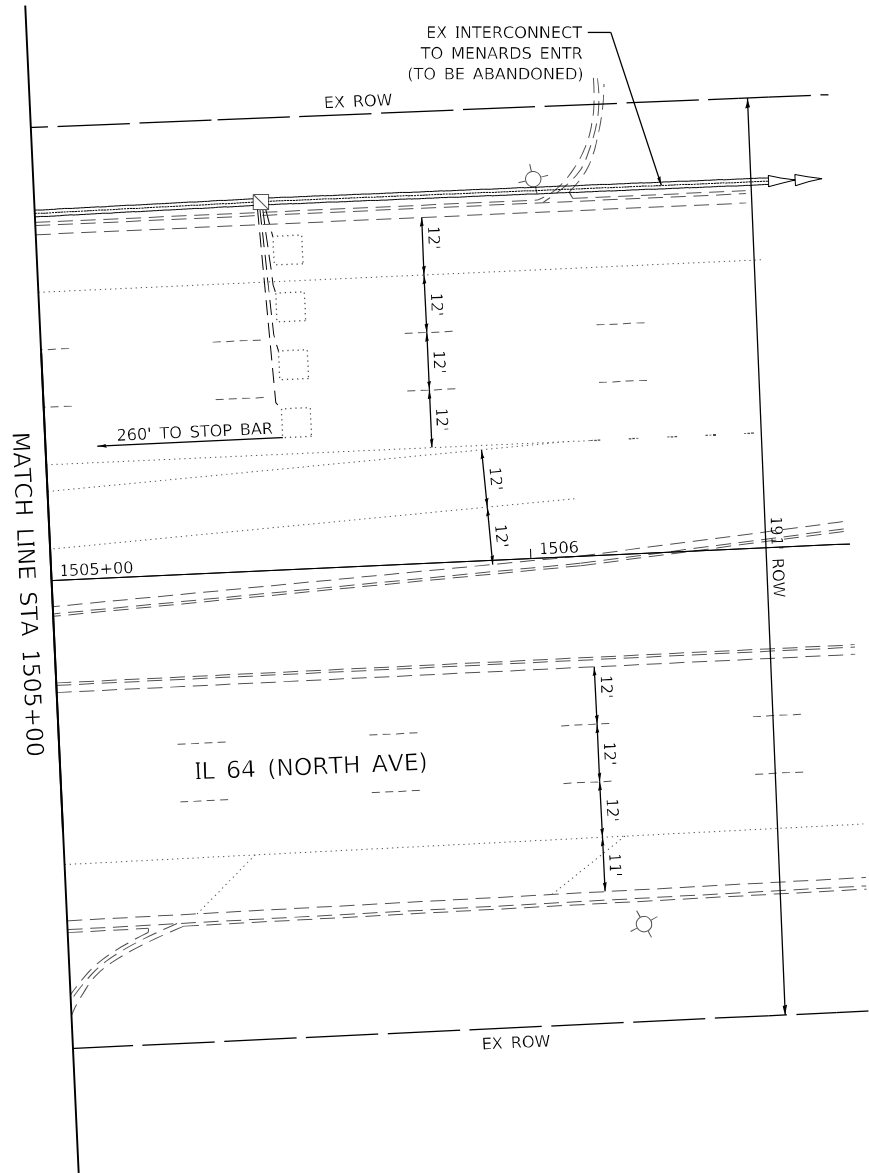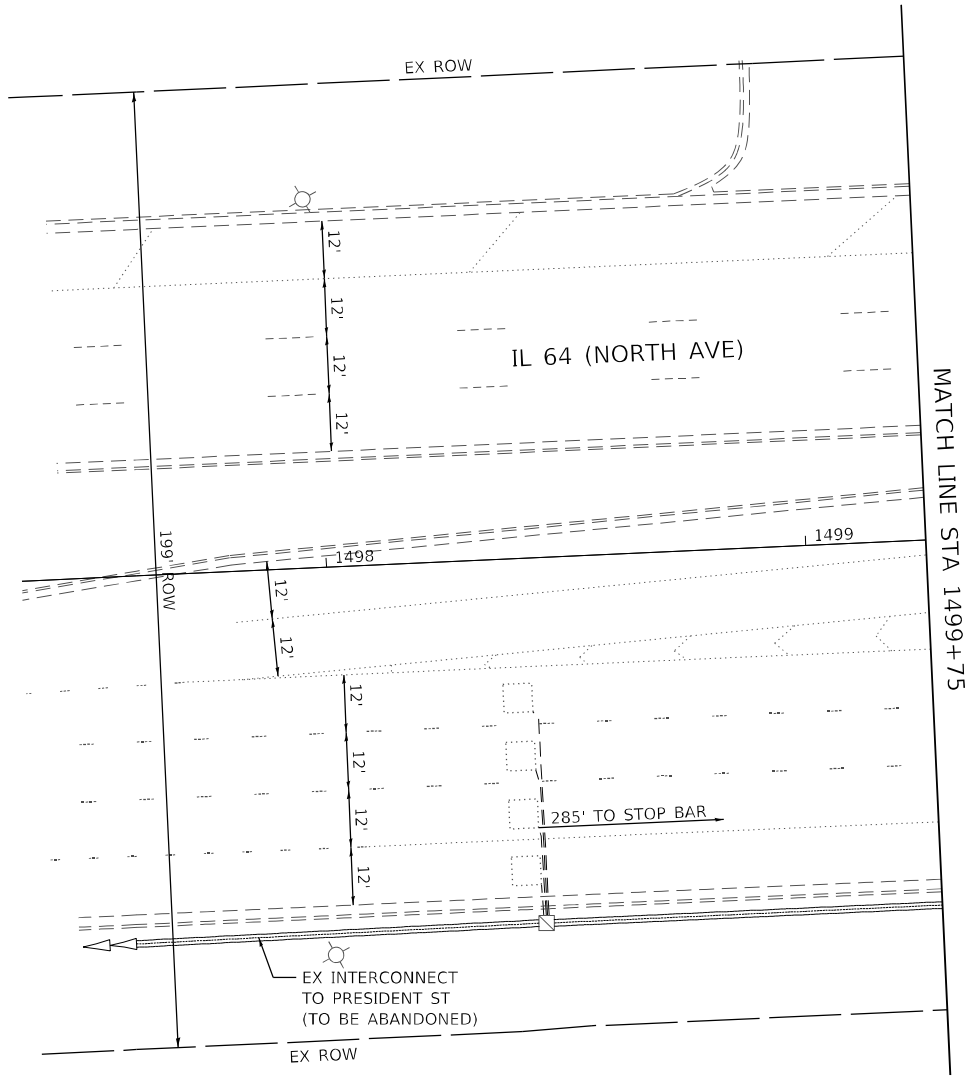

TS 6420
IDOT TACTICS
FORMER EAGLE 2E

NOTES

1. ALL PROPOSED TRAFFIC SIGNAL CABLE SHALL BE ROUTED THROUGH THE PROPOSED CONDUIT.
2. A SEPARATE LEAD-IN CABLE SHALL BE INSTALLED FOR THE DETECTOR LOOPS ON IL 64 (NORTH AVE).
3. THERE SHALL BE A MINIMUM OF 4' SIDEWALK CLEARANCE IN FRONT/BEHIND OF THE TRAFFIC SIGNAL FOUNDATIONS TO BE ADA COMPLIANT.
4. THE SIDEWALK CURBS ON ALL QUADRANTS SHALL BE CUT SO THAT THE POST AND MAST ARM FOUNDATIONS ARE FLUSH WITH THE EDGE OF THE SIDEWALK.
5. ALL PUSH BUTTONS SHALL BE APS.
6. THIS LOCATION HAS BEEN DESIGNED TO BE ADA COMPLIANT. ANY DEVIATION FROM THIS PLAN FOR THE POSTS THAT HAVE PEDESTRIAN EQUIPMENT WILL HAVE TO BE APPROVED BY THE ENGINEER TO ENSURE ADA COMPLIANCE.
7. CONTRACTOR SHALL VERIFY THAT THE PLACEMENT OF THE PROPOSED SIGNAL EQUIPMENT ADJACENT TO EXISTING RAMPS MEET ADA REQUIREMENTS. THE ENGINEER SHALL APPROVE THE PROPOSED LOCATIONS OF THE SIGNAL EQUIPMENT BEFORE INSTALLATION.

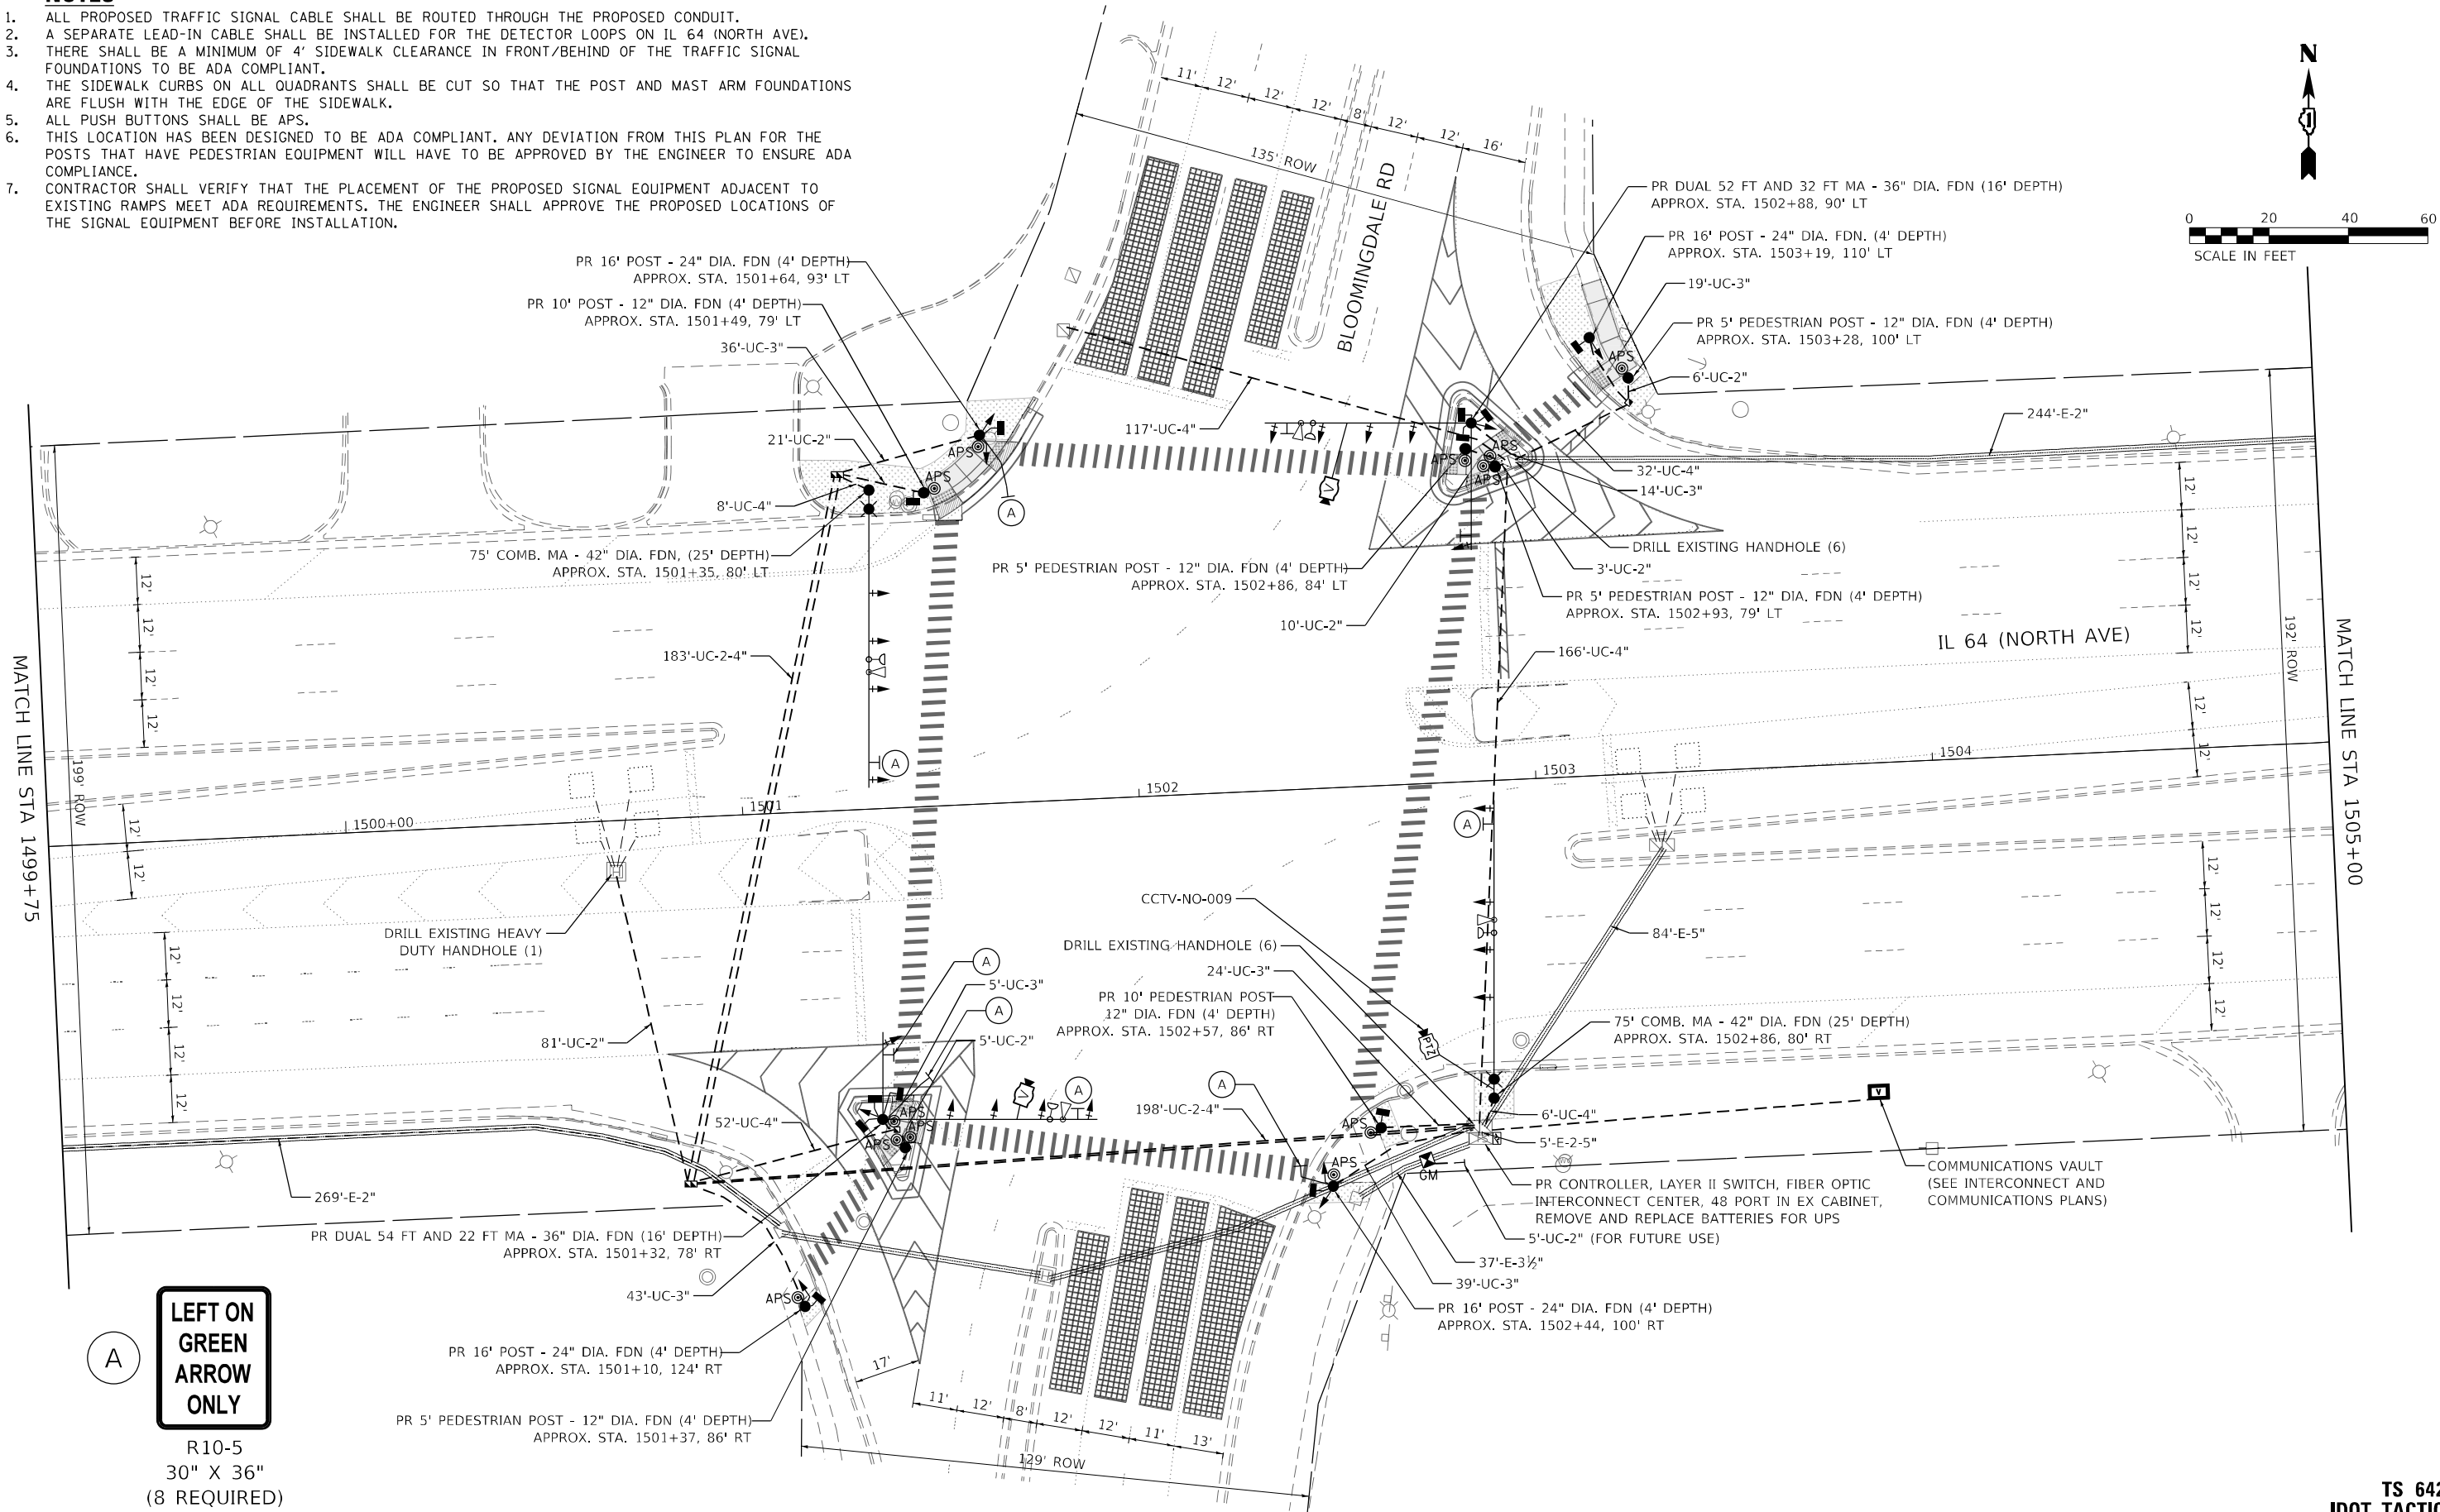

MODEL: Default
FILE: \\usmc-prod\h-pw-bentley.com\h-pw-d\1\Documents\01 Active Projects\TMC\GIS-680950\00 - IL 64\Phase II\2 Design\CAD\Plan_Sheets\Signal\West_Corridor_Signals\01081714-IL-64-92_KIM.dgn

KimleyHorn

© 2023 KIMLEY-HORN AND ASSOCIATES, INC.
4001 WILHELM D. ROAD, SUITE 600
WARREN, IL 60555
PHONE: (847) 455-4555
WWW.KIMLEY-HORN.COM

USER NAME =
DESIGNED -
DRAWN -
PLOT SCALE =
PLOT DATE =

DESIGNED -
DRAWN -
CHECKED -
DATE -

REVISED -
REVISED -
REVISED -
REVISED -

STATE OF ILLINOIS
DEPARTMENT OF TRANSPORTATION

TRAFFIC SIGNAL MODERNIZATION PLAN
IL 64 (NORTH AVE) AND BLOOMINGDALE RD

SCALE: 1" = 20' SHEET OF SHEETS STA. TO STA.

F.A.P. RTE.	SECTION	COUNTY	TOTAL SHEETS	SHEET NO.
307	2020-263-SUR, SW&TS	DUPAGE	529	193
CONTRACT NO. 62N33				
ILLINOIS FED. AID PROJECT				

TS 6420
IDOT TACTICS
FORMER EAGLE 2E

MODEL: Default
FILE NAME: p:\work\pva\bartley.com\khp\pva\011\Documents\01 Active Projects\IMW\CHS-168959\00 - IL 64\Phase II\2 Design\CAD\Plan_Sheets\Signal\West Corridor_Signal\01081714-IL-64.dgn






USER NAME	=	DESIGNED	-
DRAWN	-	REVIS	-
PLOT SCALE	=	CHECKED	-
PLOT DATE	=	DATE	-

STATE OF ILLINOIS
DEPARTMENT OF TRANSPORTATION


TRAFFIC SIGNAL MODERNIZATION PLAN IL 64 (NORTH AVE) AND BLOOMINGDALE RD			
SCALE: 1" = 20'	SHEET	OF	SHEETS
STA.	TO	STA.	TO

F.A.P. RTE.	SECTION	COUNTY	TOTAL SHEETS	SHEET NO.
307	2020-263-SUR,SW&TS	DUPAGE	529	194
CONTRACT NO. 62N33				
ILLINOIS FED. AID PROJECT				


TS 6420
IDOT TACTICS
FORMER EAGLE 2E

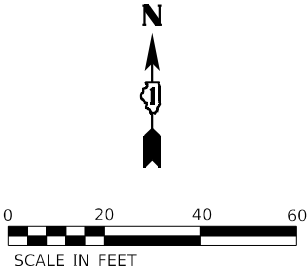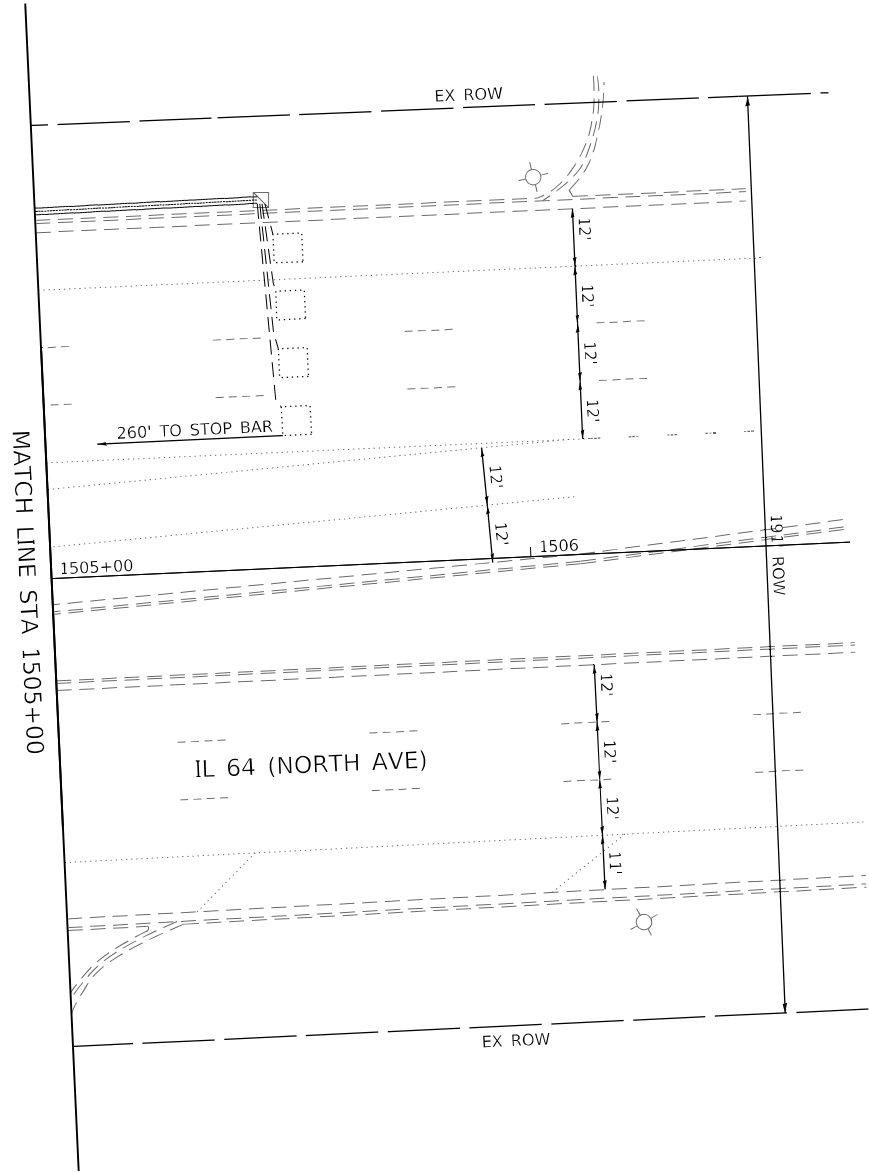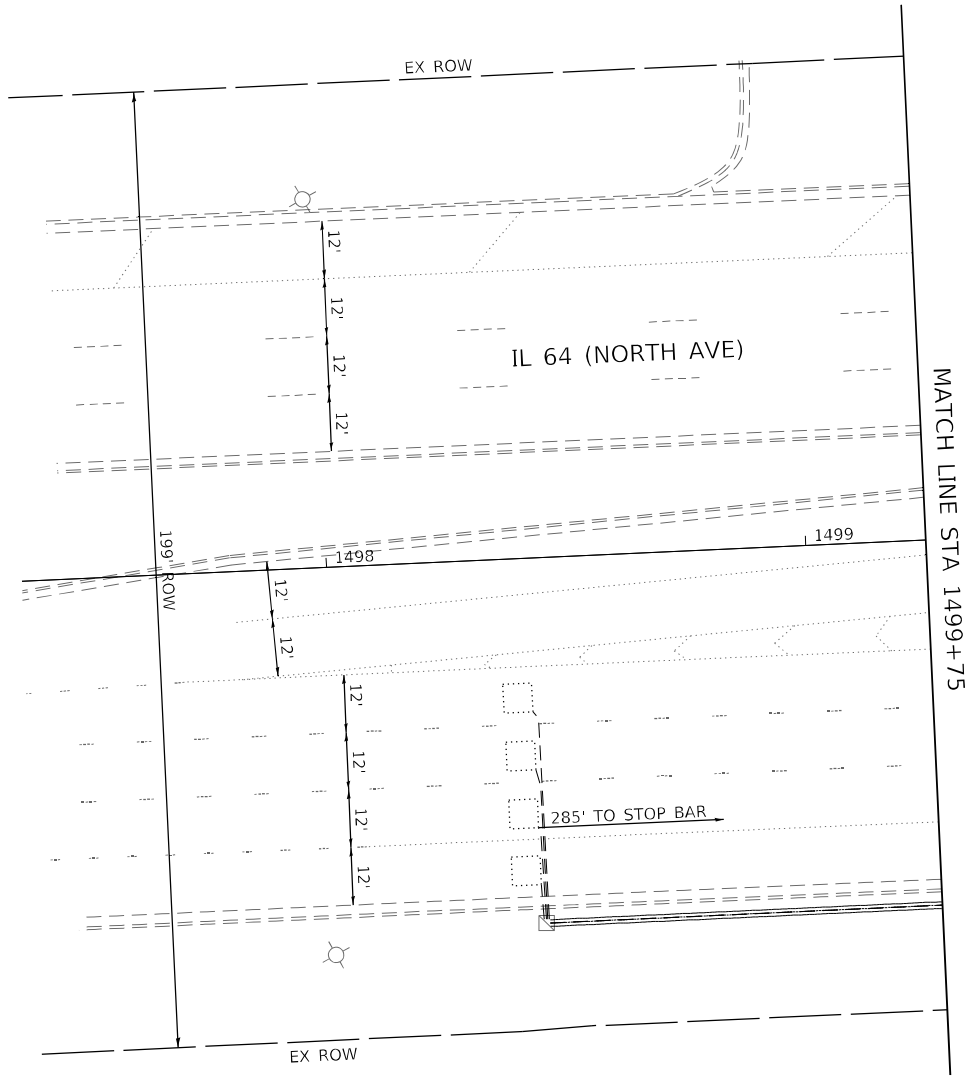

EXISTING CONTROLLER SEQUENCE

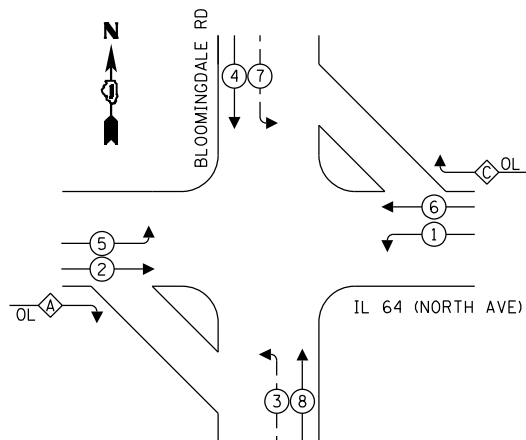


PROPOSED
CONTROLLER SEQUENCE

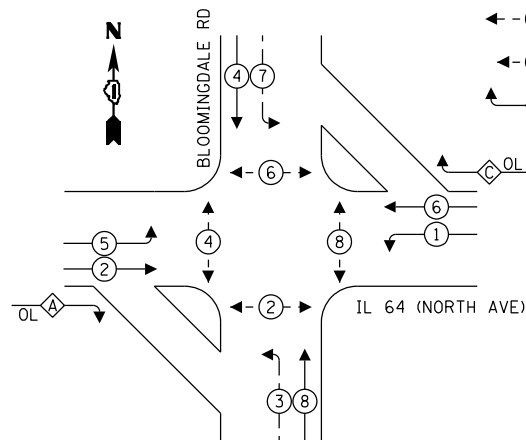

LEGEND:

-  PROTECTED PHASE
 PROTECTED/PERMITTED PHASE
 PEDESTRIAN PHASE
 OVERLAP

EXISTING AND PROPOSED EMERGENCY VEHICLE PREEMPTION SEQUENCE

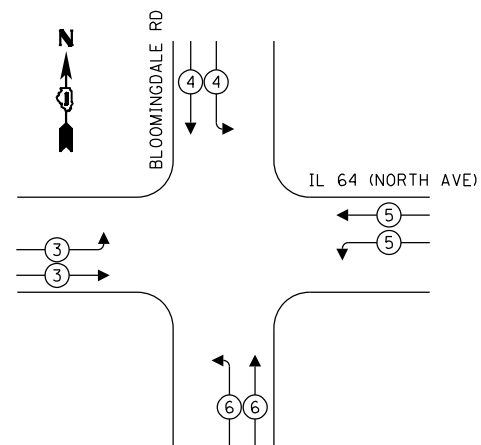

TRAFFIC SIGNAL ELECTRICAL SERVICE REQUIREMENTS


TYPE	QUANTITY	UNIT WATTAGE	TOTAL WATTAGE
SIGNAL HEAD 1 OR 3-SECTION	22	11	242
4-SECTION	-	14	-
5-SECTION	4	13	52
PROGRAMMABLE 3-SECTION	-	22	-
4-SECTION	-	32	-
5-SECTION	-	28	-
PEDESTRIAN SIGNAL	12	15	180
CONTROLLER	1	150	150
MASTER CONTROLLER	-	100	-
UPS	1	25	25
DETECTION VIDEO	2	20	40
BLANK-OUT SIGN	-	25	-
NETWORK SWITCH LAYER II OR III	1	35	35
CELLULAR MODEM	-	15	-
PTZ	1	75	75
TOTAL UPS SIZING			799
UPS CHARGING	1	225	225
BATTERY HEATER MAT	1	180	180
CABINET HEATER	1	200	200
FLASHER	-	15	-
LED STREET NAME SIGN	-	120	-
LUMINAIRE	-	240	-

ENERGY COSTS TO:
ILLINOIS DEPARTMENT OF TRANSPORTATION
201 W CENTER CT
SCHAUMBURG, IL 60196

ENERGY SUPPLY: COMPANY: COMED
PHONE: (866) 639-3532
ACCOUNT NUMBER: 60180-18058

LEGEND:

* = ROADWAY LIGHTING CABLE

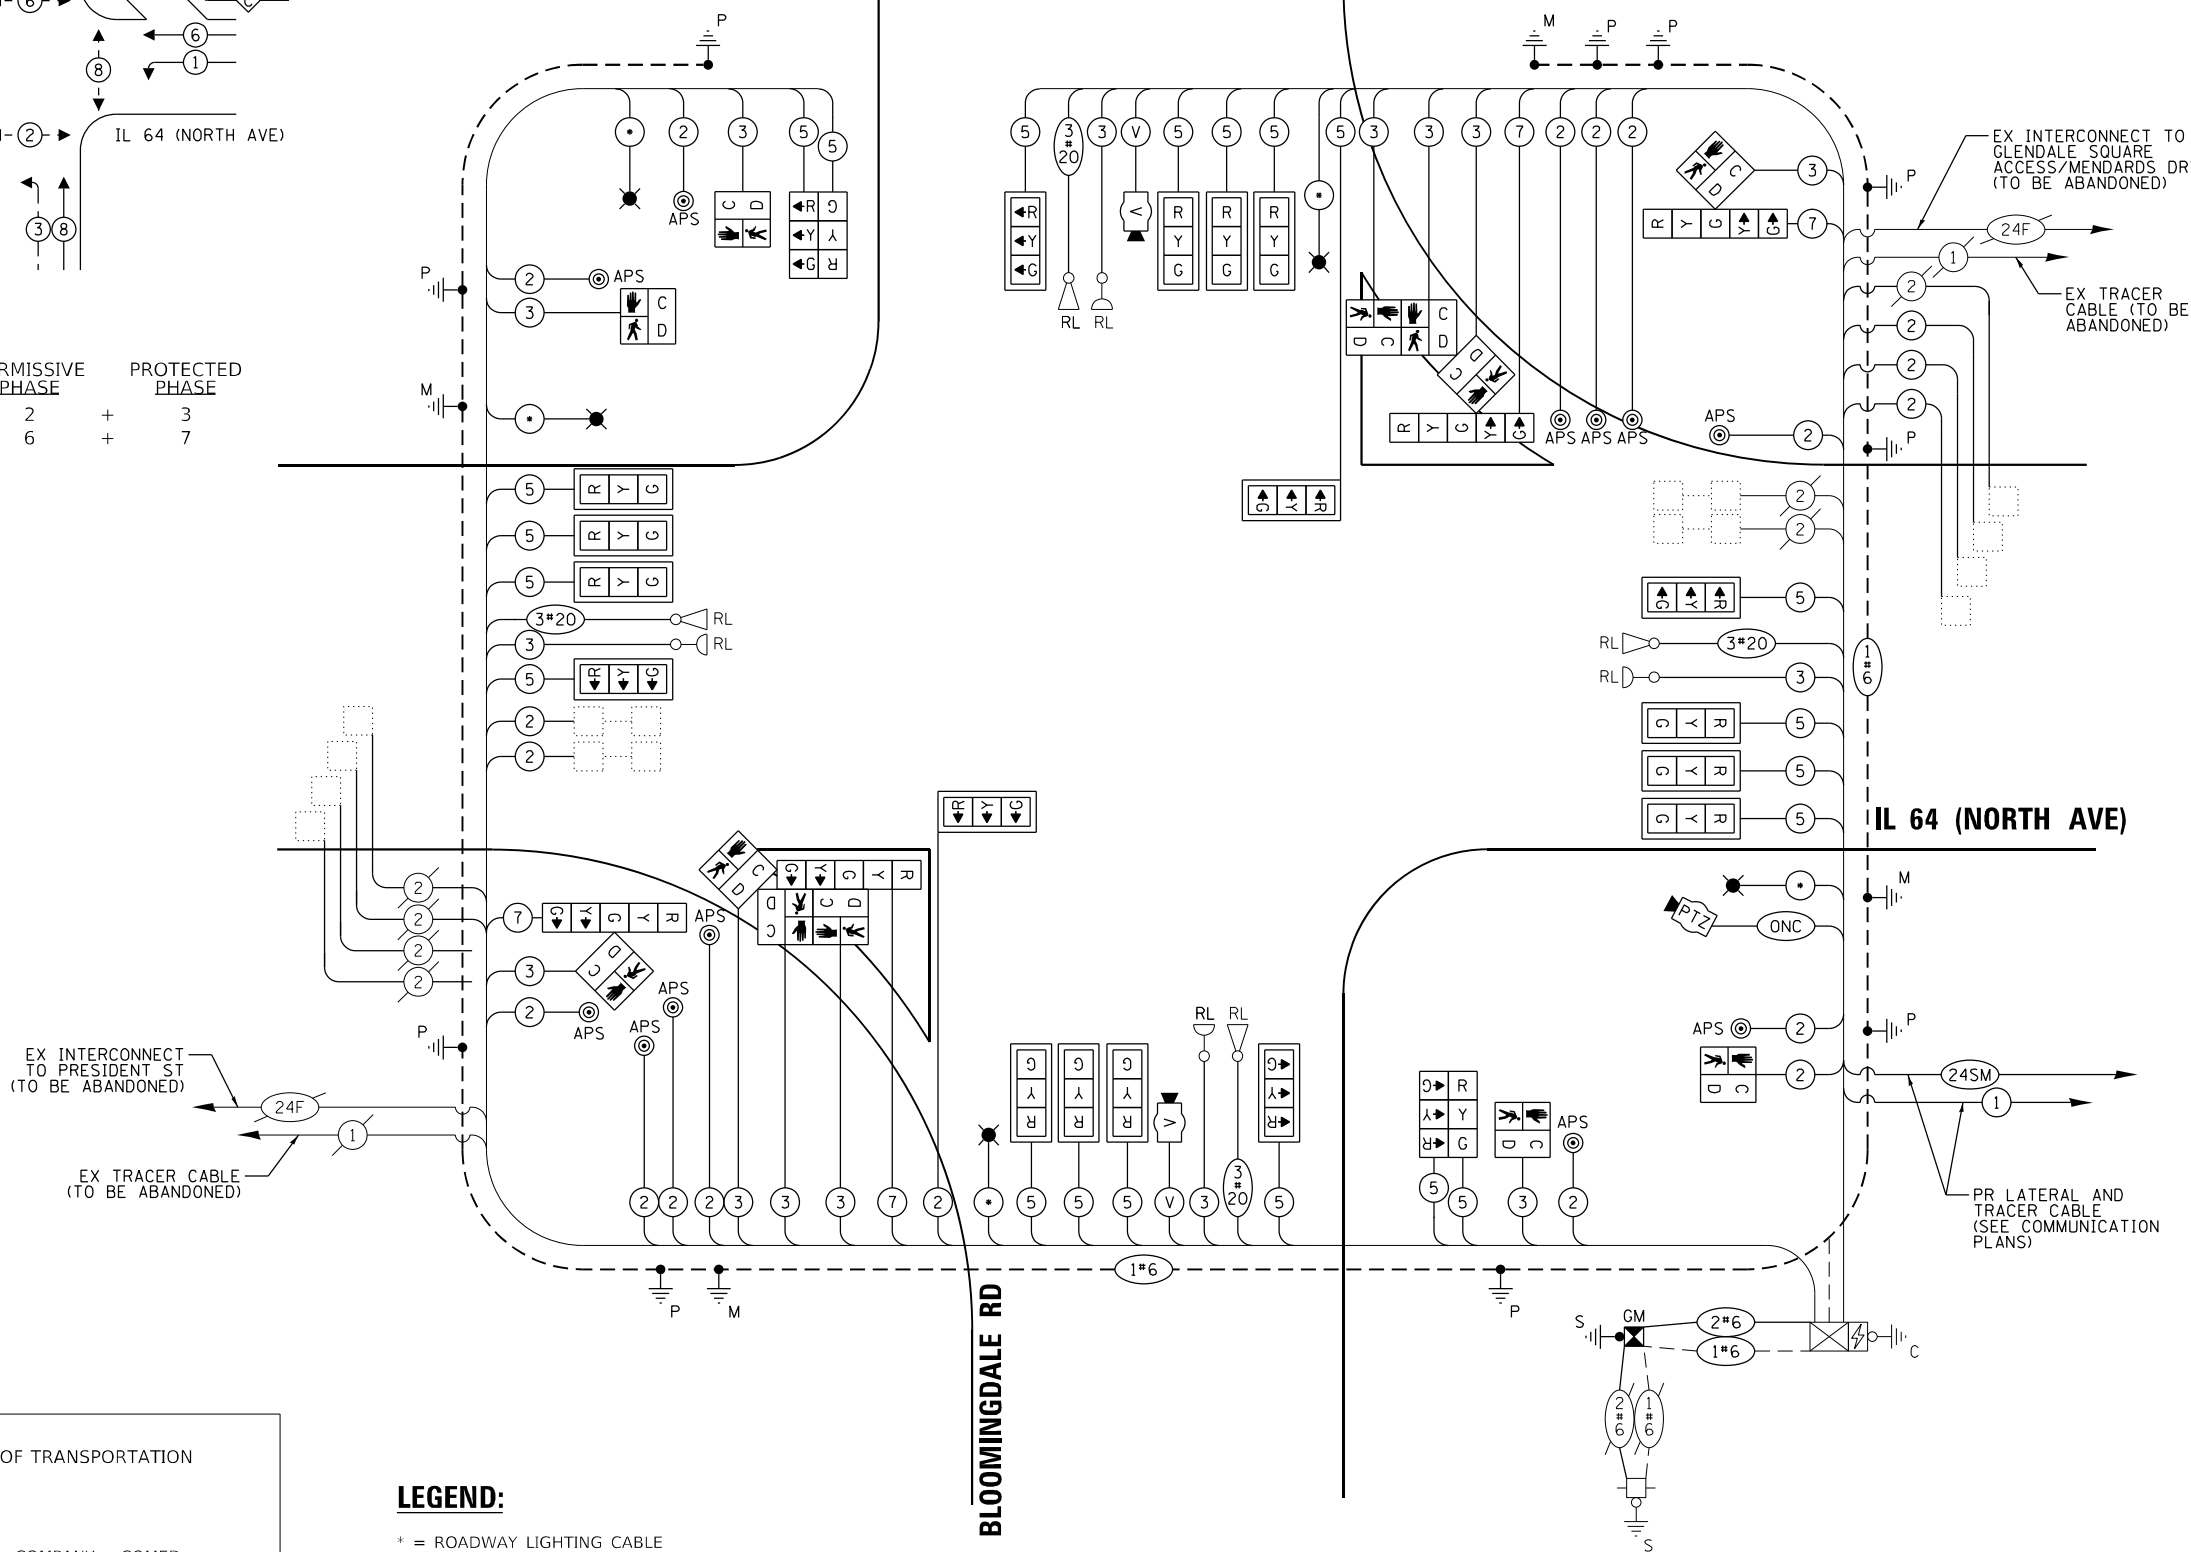

CABLE PLAN

(NOT TO SCALE)

TS 6420
IDOT TACTICS
FORMER EAGLE 2E

**CABLE PLAN, PHASE DESIGNATION DIAGRAM, AND
EMERGENCY VEHICLE PREEMPTION SEQUENCE
IL 64 (NORTH AVE) AND BLOOMINGDALE RD**

SCALE:	SHEET	OF	SHEETS	STA.	TO STA.
--------	-------	----	--------	------	---------

F.A.P. RTE.	SECTION	COUNTY	TOTAL SHEETS	SHEET NO.
307	2020-263-SUR,SW&TS	DUPAGE	529	195
		CONTRACT NO. 62N33		
		ILLINOIS FED. AID PROJECT		

Kimley»Horn

© 2023 KIMLEY-HORN AND ASSOCIATES, INC.
4201 WINTFIELD ROAD, SUITE 603
WARRENVILLE, IL 60555
PHONE: 630-487-5550
WWW.KIMLEY-HORN.COM

USER NAME	=
PLOT SCALE	=
PLOT DATE	=



DESIGNED -
DRAWN -
CHECKED -
DATE -

REVISED	-
REVISED	-
REVISED	-
REVISED	-

**STATE OF ILLINOIS
DEPARTMENT OF TRANSPORTATION**


MODEL: Default
FILE NAME: pw:\kh-pw\bentlev.com\kh-pw-01\Documents\01 Active Projects\MW-CHS-16895100 - IL 64\Phase II\2 Design\CAD\Plan Sheets\Signals\West Corridor Signals\ID1081121-sht-ts-94_KHA.dgn

  ALL DIMENSIONS ARE IN INCHES UNLESS OTHERWISE NOTED



* - 100% COST TO THE VILLAGE OF GLENDALE HEIGHTS

1. THE EXISTING TRAFFIC SIGNAL EQUIPMENT SHALL NOT BE REMOVED UNTIL THE PROPOSED TRAFFIC SIGNAL EQUIPMENT IS FULLY OPERATIONAL OR AS DIRECTED BY THE ENGINEER.
2. ALL EXISTING TRAFFIC SIGNAL CABLE NO LONGER REQUIRED SHALL BE REMOVED.

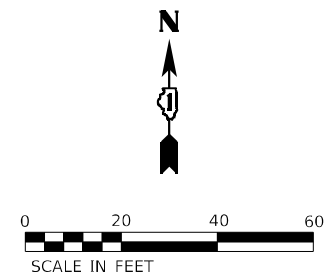

THE FOLLOWING ITEMS SHALL BE REMOVED BY THE CONTRACTOR AND SHALL BE DISPOSED OF BY THEM OUTSIDE THE RIGHT-OF-WAY AT THEIR EXPENSE. THE SALVAGE VALUE OF THE REMOVED EQUIPMENT SHALL BE REFLECTED IN CONTRACT BID PRICE.

14	EACH	SIGNAL HEAD, 1 FACE, 3 SECTION
8	EACH	SIGNAL HEAD, 1 FACE, 5 SECTION
1	EACH	CONTROLLER (M52)
4	EACH	CONFIRMATION BEACON
4	EACH	LIGHT DETECTOR
1	EACH	LIGHT DETECTOR AMPLIFIER
12	EACH	TRAFFIC SIGNAL BACKPLATE
2	EACH	TRAFFIC SIGNAL POST
2	EACH	COMBINATION MAST ARM ASSEMBLY AND POLE
2	EACH	COMBINATION DUAL MAST ARM ASSEMBLY AND POLE

TS 11390
IDOT TACTICS
FORMER EAGLE 2E



USER NAME	DESIGNED	REVISED
	DRAWN	REVISED
PLOT SCALE	CHECKED	REVISED
PLOT DATE	DATE	REVISED

**STATE OF ILLINOIS
DEPARTMENT OF TRANSPORTATION**

TRAFFIC SIGNAL EQUIPMENT REMOVAL PLAN
IL 64 (NORTH AVE) AND GLENDALE SQUARE ACCESS / MENARDS ENTR

SCALE: 1" = 20'	SHEET	OF	SHEETS	STA.	TO STA.
-----------------	-------	----	--------	------	---------

F.A.P. RTE.	SECTION	COUNTY	TOTAL SHEETS	SHEET NO.
307	2020-263-SUR, SW&TS	DUPAGE	529	197
		CONTRACT NO. 62N333		
		ILLINOIS	FED. AID PROJECT	

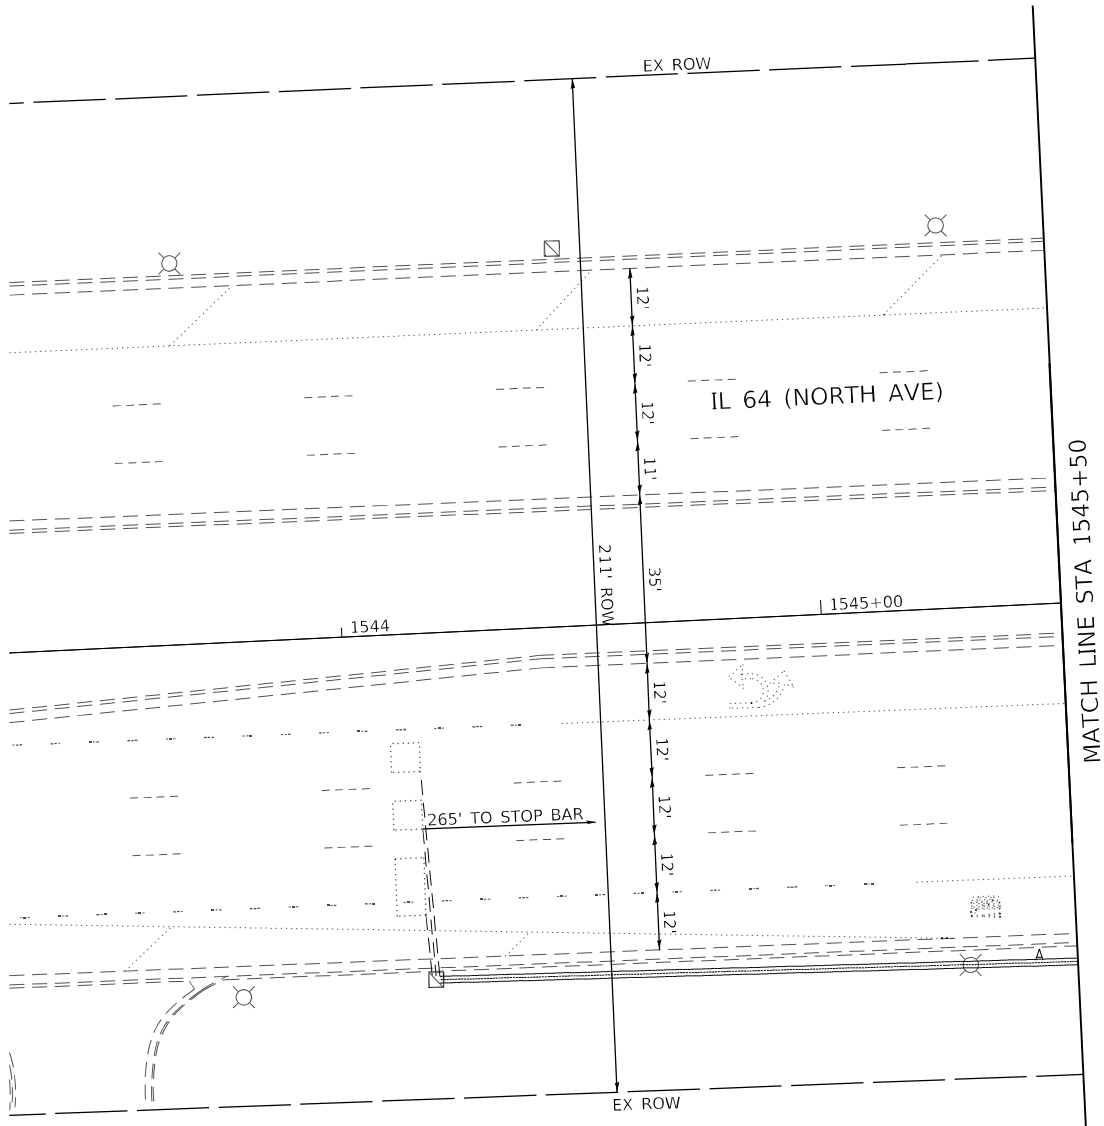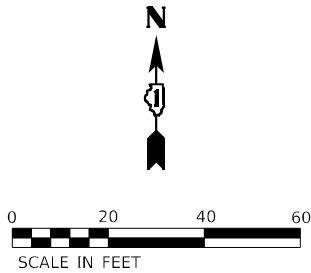

MODEL: Default
FILE NAME: p:\sub-pw\bartley.com\k-h-pw-d1\Documents\01 Active Projects\MW\CL-S-160950\00 - IL 64\Phase II\2 Design\CAD\Plan Sheets\Signal\West Corridor_Signal\01\081714-IL-64-27_K44.dgn





USER NAME =	DESIGNED -	REVISED -
	DRAWN -	REVISED -
PLOT SCALE =	CHECKED -	REVISED -
PLOT DATE =	DATE -	REVISED -

STATE OF ILLINOIS
DEPARTMENT OF TRANSPORTATION

TRAFFIC SIGNAL EQUIPMENT REMOVAL PLAN			
IL 64 (NORTH AVE) AND GLENDALE SQUARE ACCESS / MENARDS ENTR			
SCALE: 1" = 20'	SHEET	OF SHEETS	STA. TO STA.

F.A.P. RTE.	SECTION	COUNTY	TOTAL SHEETS	SHEET NO.
307	2020-263-SUR,SW&TS	DUPAGE	529	198
CONTRACT NO. 62N33				
		ILLINOIS	FED. AID PROJECT	

TS 11390
IDOT TACTICS
FORMER EAGLE 2E

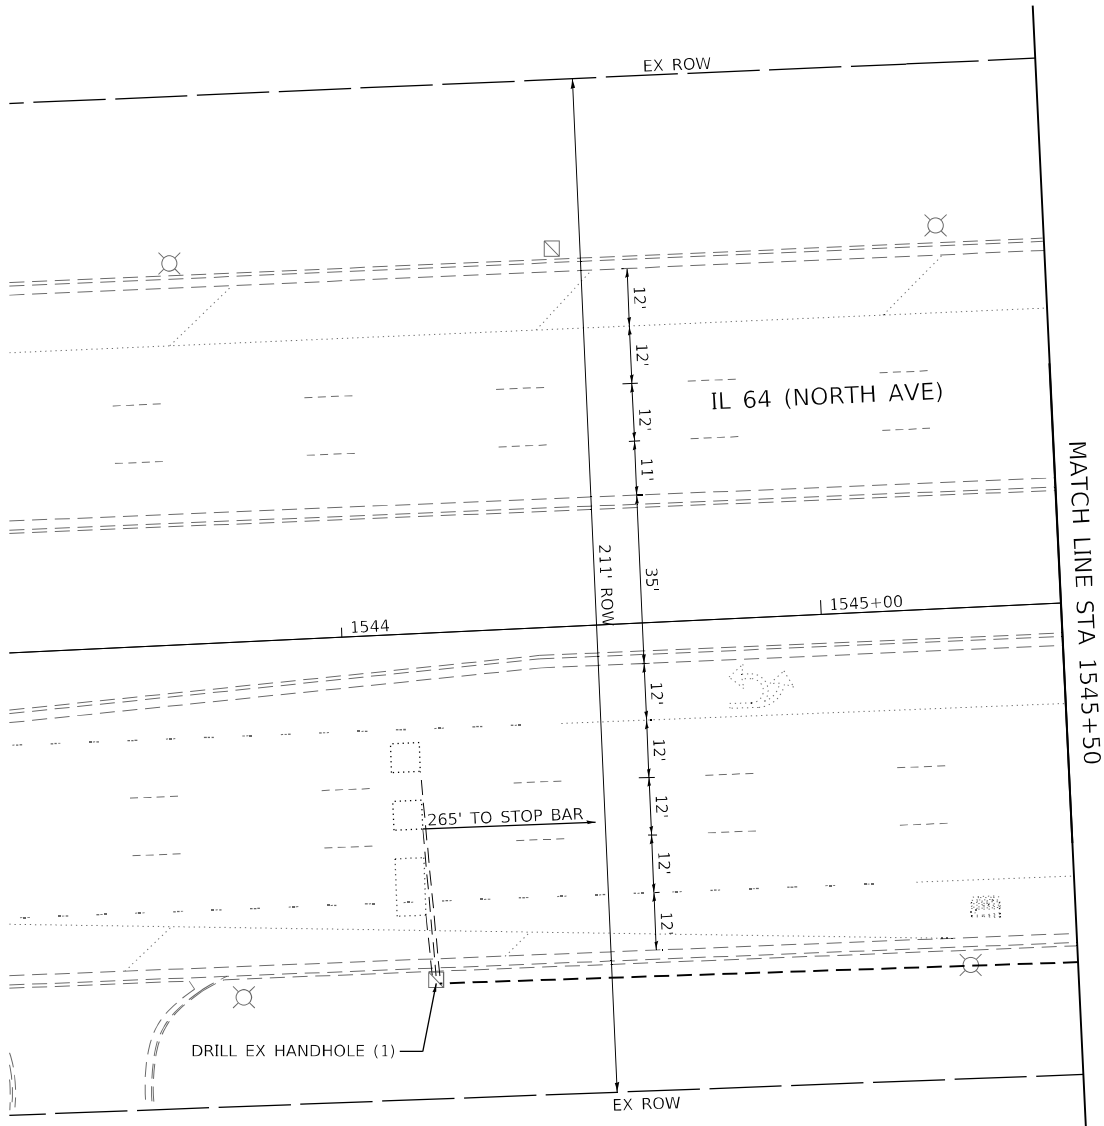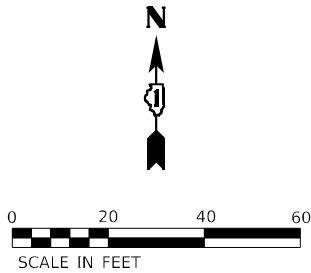

MODEL: Default
FILE: h:\mhc\projects\pva\bartley.com\h-pva-d1\Documents\01 Active Projects\MW\CHS-168950\00 - IL 64\Phase II\2 Design\CAD\Plan Sheets\Signal\West Corridor_Signal\010817-14-11-15-99_K44.dgn



USER NAME =	DESIGNED -	REVISED -
	DRAWN -	REVISED -
PLOT SCALE =	CHECKED -	REVISED -
PLOT DATE =	DATE -	REVISED -

STATE OF ILLINOIS
DEPARTMENT OF TRANSPORTATION

TRAFFIC SIGNAL MODERNIZATION PLAN			
IL 64 (NORTH AVE) AND GLENDALE SQUARE ACCESS / MENARDS ENTR			
SCALE: 1" = 20'	SHEET	OF SHEETS	STA. TO STA.

F.A.P. RTE.	SECTION	COUNTY	TOTAL SHEETS	SHEET NO.
307	2020-263-SUR,SW&TS	DUPAGE	529	200
CONTRACT NO. 62N33				
		ILLINOIS	FED. AID PROJECT	

TS 11390
IDOT TACTICS
FORMER EAGLE 2E