


CITY OF MACOMB, ILLINOIS  
PUBLIC WORKS DEPARTMENT  
233 CENTER STREET  
MACOMB, ILLINOIS 61455  
(309) 833-2821

TYPICAL WATER SERVICE  
METER DETAIL

DATE: 9/27/2012  
CHECKED: KC/AB  
SHEET NO.  
1  
of 1

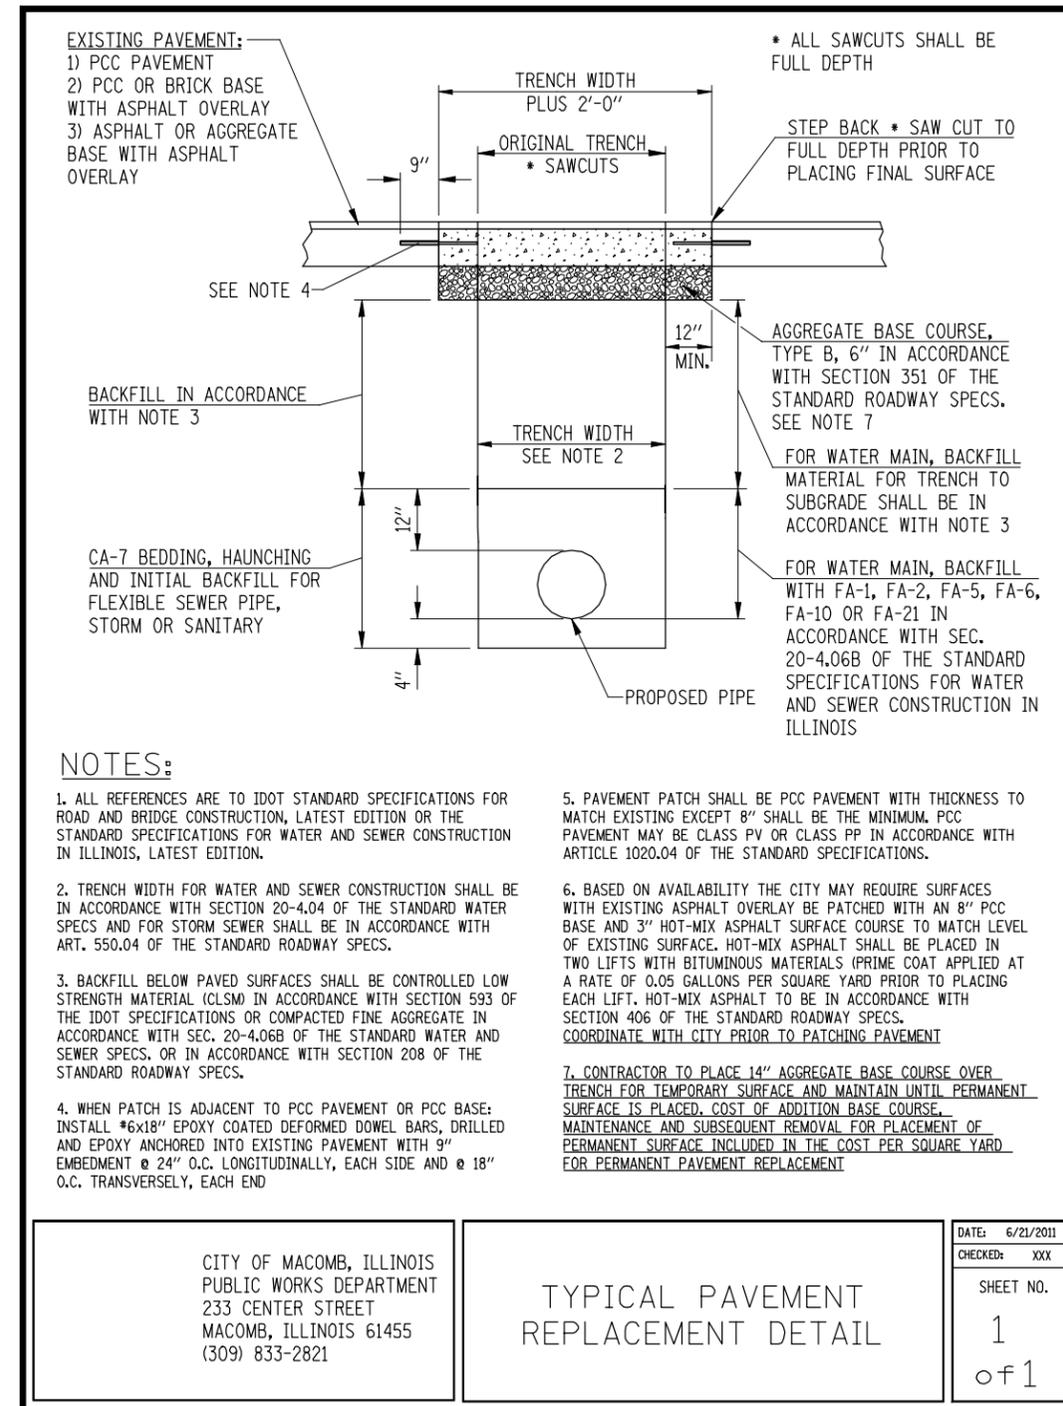

CITY OF MACOMB, ILLINOIS  
PUBLIC WORKS DEPARTMENT  
233 CENTER STREET  
MACOMB, ILLINOIS 61455  
(309) 833-2821

TYPICAL PAVEMENT  
REPLACEMENT DETAIL

DATE: 6/21/2011  
CHECKED: XXX  
SHEET NO.  
1  
of 1

FILE NAME =	USER NAME = jdeen	DESIGNED - JRB	REVISED -
v:\transportation\2891\grading plans\W001.dgn		DRAWN - RLR	REVISED -
	PLOT SCALE = 1/80' / IN.	CHECKED - AWM	REVISED -
	PLOT DATE = 12/12/2012	DATE - 12-12-12	REVISED -

STATE OF ILLINOIS  
DEPARTMENT OF TRANSPORTATION

FAP 407 (IL RTE 336) UTILITY SPECIAL DETAILS		F.A.P. RTE. 407	SECTION (55-3)A	COUNTY McDONOUGH	TOTAL SHEETS 671	SHEET NO. 176
SCALE: 1"=50	SHEET NO. 3 OF 4 SHEETS	STA.	TO STA.	ILLINOIS FED. AID PROJECT		

F.A.P. RTE. 407	SECTION (55-3)A	COUNTY McDONOUGH	TOTAL SHEETS 671	SHEET NO. 176
CONTRACT NO. 68A42				
ILLINOIS FED. AID PROJECT				