
COUNTY TOTAL SHEET NO.

COOK 976 228 SECTION 90/94 2003-0311 STA. 1321+00 TO STA. 1334+00 $\rightarrow \bigcirc \rightarrow Z$ FED. ROAD DIST. NO. ILLINOIS FED. AID PROJECT 62583

NOTES:

- 1. SEE DRAWINGS ME-01 AND ME-02 FOR ELECTRICAL SYMBOLS AND ABBREVIATIONS.
- UNLESS NOTED OTHERWISE, ALL ITEMS AND WORK SHOWN IN HEAVY LINE WEIGHT ON THIS DRAWING ARE PROPOSED NEW ITEMS OF WORK.
- 3. THE EXISTING ROADWAY LIGHTING SYSTEM SHALL REMAIN IN OPERATION UNTIL THE PROPOSED ROADWAY LIGHTING SYSTEM HAS BEEN INSTALLED, ENERGIZED, TESTED, AND ACCEPTED BY THE ENGINEER, UNLESS OTHERWISE DIRECTED BY THE ENGINEER.
- 4. REMOVAL OF LIGHT POLE AND LUMINAIRE ARE PART OF CONTRACT 62583. FOUNDATION REMOVAL SHALL BE BY OTHERS.

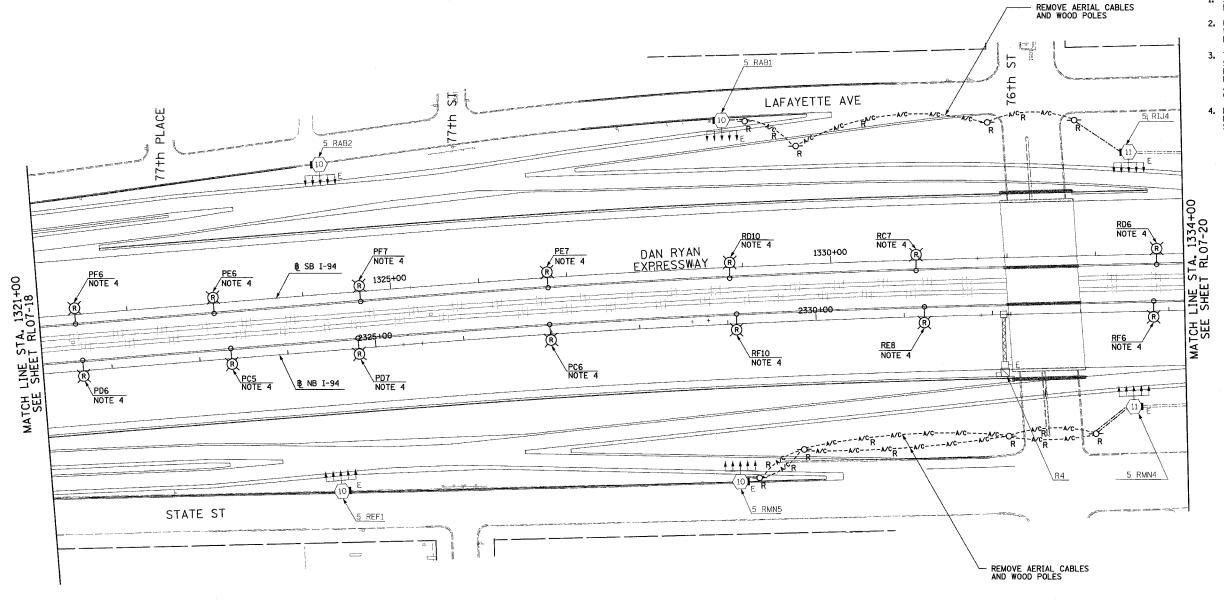

0 50' 10 1" = 50'

RL07-19

REVISIONS	ILLINOIS DEPARTMENT OF TRANSPORTATION						
NAME	DATE	ILLENOIS DEPARTMENT OF TRANSPORTATION					
		F.A.I.	90/94	(DAN	RYAN	EXPRES	SWAY)
		31st STREET TO I-57					
		ROADWAY LIGHTING PLANS PROPOSED IMPROVEMENTS 2007					
		CONT	1//-50/			00.4884 04	

SCALE: 1"=50" 01/21/05 DATE: OCTOBER 29, 2004 DRAWN BY: VG

SINGH & ASSOCIATES, INC.
CONSULTING ENGINEERS

SINCH & ASSOCIATES, INC.
CONSULTING ENGINEERS

TAX: (312) 629-0240
FAX: (312) 629-8449