
F.A.I. RTE.	SECTIO	N	COUN	ľΥ	TOTAL	SHEE'
90/94	2003-0311		COOK		976	230
STA.	1347+00	TO	STA.	1360	+00	
FED. RO	AD DIST. NO.	ILLINOIS	FED.	AID	PROJECT	•
					6	258

→�→Z

- 1. SEE DRAWINGS ME-01 AND ME-02 FOR ELECTRICAL SYMBOLS AND ABBREVIATIONS.
- UNLESS NOTED OTHERWISE, ALL ITEMS AND WORK SHOWN IN HEAVY LINE WEIGHT ON THIS DRAWING ARE PROPOSED NEW ITEMS AND WORK.
- 3. THE EXISTING ROADWAY LIGHTING SYSTEM SHALL REMAIN IN OPERATION UNTIL THE PROPOSED ROADWAY LIGHTING SYSTEM HAS BEEN INSTALLED, ENERGIZED, TESTED, AND ACCEPTED BY THE ENGINEER, UNLESS OTHERWISE DIRECTED BY THE ENGINEER,

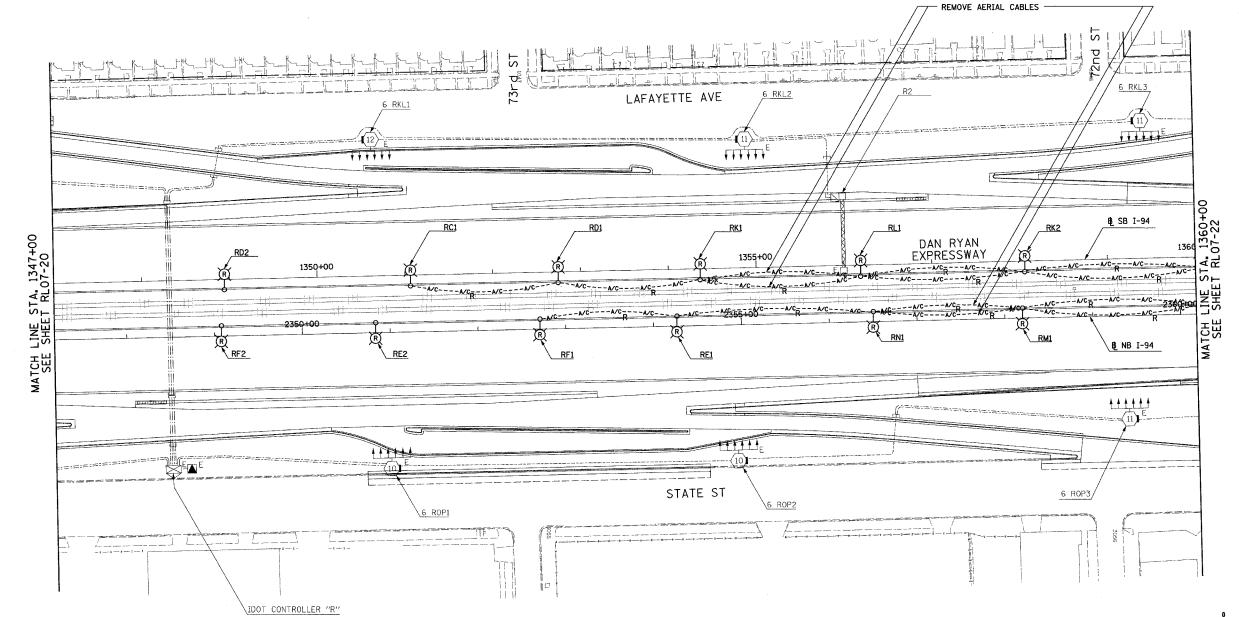

RL07-21

REVISIO	ILLINOIS DEPARTMENT OF TRANSPORTATION						
NAME	DATE	155	ANSFORTATION				
		F.A.I.	90/94	(DAN	RYAN	EXPRESSWAY	
		31st STREET TO I-57					
		l	. 51				
		ROADWAY LIGHTING PLANS					
		1				TLANS	

SCALE: 1"=50'

DRAWN BY: VG CHECKED BY: TM

SINGH & ASSOCIATES, INC. TEL: (312) 629-0240 CONSULTING ENGINEERS FAX: (312) 629-8449