
COUNTY F.A.P. RTE. SECTION 305 1313.1 B COOK 193 121 TO STA. FED. AID PROJECT: FED. ROAD DIST. NO. ILLINOIS

CONTRACT NO. 62878

TEMPORARY SEQUENCE OF OPERATION

MOVEMENT			- ካ 1 ተ	⊢	1	^	↑	↑	_	→	J	_ ⊢ T	-1	<u> </u>	*	1 T	:	F
PHASE			1			2				3			4					L
INTERVAL		1	2A	2B	3	4A	4B	4C	4D	5	6A	6B	7	8A	8B	8C	8D	Α
CHANGE TO			2			3			4			1				S H		
ILLLINOIS ROUTE 83 (ELMHURST ROAD) NEAR AND FAR RIGHT SIGNALS AT EB FRONTAGE ROAD	N/B	Ĝ G→	Υ	R	R	R	R	R	R	R	R	R	R	R	R	R	R	R
ILLLINOIS ROUTE 83 (ELMHURST ROAD) FAR LEFT SIGNAL AT EB FRONTAGE ROAD	N/B	Ĝ	Υ	R	R	R	R	R	R	R	R	R	R	R	R	R	R	R
ILLLINOIS ROUTE 83 (ELMHURST ROAD) FAR SIDE SIGNALS AT WB FRONTAGE ROAD	N/B	∳ G G-G	† GG	¢o¢	∳ G G	4 υ 4	40€	Υ	R	R	R	R	R	R	R	R	R	R
ILLLINOIS ROUTE 83 (ELMHURST ROAD) NEAR AND FAR RIGHT SIGNALS AT WB FRONTAGE ROAD	S/B		R	R	R	R	R	R	R	Ĝ G→	Y	R	R	R	R	R	R	R
ILLLINOIS ROUTE 83 (ELMHURST ROAD) FAR LEFT SIGNAL AT WB FRONTAGE ROAD	S/B	R	R	R	R	R	R	R	R	ŧ	Y	R	R	R	R	R	R	R
ILLINOIS ROUTE 83 (ELMHURST ROAD) FAR SIDE SIGNALS AT EB FRONTAGE ROAD	S/B	R	R	R	R	R	R	R	R	† G	♣ G	 GGG	 CGG	† G	‡ G	Υ	R	R
EASTBOUND FRONTAGE ROAD NEAR SIDE SIGNAL	E/B	R	R	R	G	Y	R	R	R	R	R	R	R	R	R	R	R	R
EASTBOUND FRONTAGE ROAD FAR SIDE SIGNALS	E/B	R	R	R	G ← G	Υ	R	R	R	R	R	R	R	R	R	R	R	R
WESTBOUND FRONTAGE ROAD NEAR SIDE SIGNAL	₩/B	R	R	R	R	R	R	R	R	R	R	R	G	Υ	R	R	R	R
WESTBOUND FRONTAGE ROAD FAR SIDE SIGNALS	W/B	R	R	R	R	R	R	R	R	R	R	R	G ← G	Υ	R	R	R	R

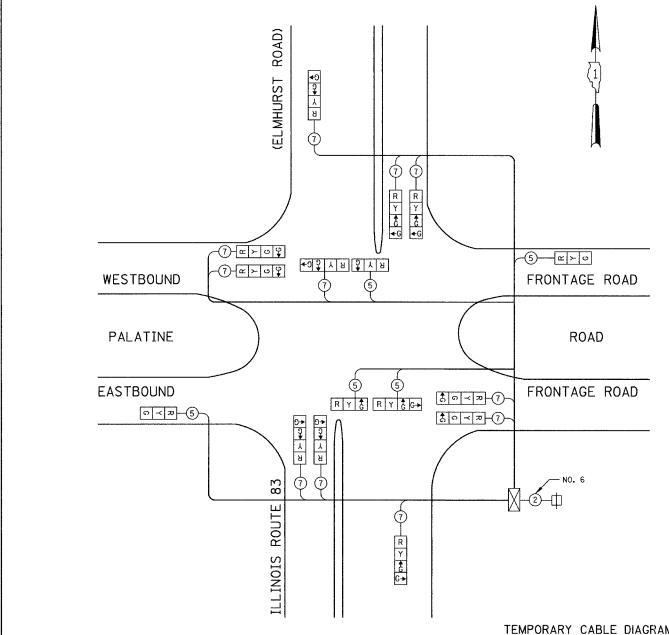

TEMPORARY CABLE DIAGRAM LEGEND

TEMPORARY CABLE PLAN NOT TO SCALE

TOTAL WATTAGE

2665.0

TOTAL =

R \bowtie

 \Box

(5)

•4

 \odot

TEMPORARY TRAFFIC SIGNAL SECTION OR PEDESTRIAN SIGNAL SECTION 12" (300mm)

TEMPORARY CONTROLLER CABINET

TEMPORARY SERVICE INSTALLATION

INDICATES NUMBER OF CONDUCTORS IN CABLE. ALL CONDUCTORS TO BE NUMBER 14 AWG WIRE UNLESS OTHERWISE NOTED.

EMERGENCY VEHICLE LIGHT DETECTOR

CONFIRMATION BEACON

VEHICLE DETECTOR, INDUCTION LOOP

PEDESTRIAN PUSHBUTTON DETECTOR

12" (300mm) PEDESTRIAN SIGNAL SECTION

MICROWAVE VEHICLE SENSOR

GANDHI AND ASSOCIATES, INC.

ILLINOIS DEPARTMENT OF TRANSPORTATION PALATINE ROAD: ILL 83 (Elmhurst Rd.) TO WISCONSIN CENTRAL RR TEMPORARY CABLE PLAN AND TEMPORARY SEQUENCE OF OPERATION ILLINOIS ROUTE 83 (ELMHURST ROAD) AT EAST AND WESTBOUND FRONTAGE ROADS TO AND FROM PALATINE ROAD

DRAWN BY: BB,ME,KP

DESIGNED BY: PKG/RRM

SCALE: N.T.S. DATE: 11/18/2004

REVISIONS

NAME

CHECKED BY: PKG/RRM

ILLINOIS DEPARTMENT OF TRANSPORTATION 201 WEST CENTER COURT SCHAUMBURG, ILLINOIS 60196-1096

ENERGY SUPPLY CONTACT: JOAN COOK PHONE: (847) 816-5461

I.D.O.T.
TRAFFIC SIGNAL INSTALLATION

PED. SIGNAL CONTROLLER ILLUM. SIGN

ENERGY COSTS TO: