INDEX OF SHEETS

57-62

63-90

SHEET NO. DESCRIPTION COVER GENERAL NOTES - STANDARDS 3-5 SUMMARY OF QUANTITIES TYPICAL SECTIONS SCHEDULE OF QUANTITIES ALIGNMENT, TIES, AND BENCHMARKS 12-14 15-17 PLAN AND PROFILE SHEETS TRAFFIC CONTROL PLAN 19-22 EROSION AND SEDIMENT CONTROL 23 - 25REMOVAL OF IMPROVEMENTS 26 - 29DRAINAGE AND UTILITIES INTERSECTION GEOMETRICS 31-33 PAVEMENT MARKING AND SIGNAGE 34 - 35LANDSCAPE PLANS LIGHTING PLANS 36-38 39-56 BRIDGE PLANS - SN 001-6012

STATE OF ILLINOIS
DEPARTMENT OF TRANSPORTATION
DIVISION OF HIGHWAYS
BUREAU OF LOCAL ROADS / STREETS


PROPOSED STREET and BRIDGE PLANS

NORTH 5th STREET BRIDGE SECTION 03-00289-00-BR PROJECT NO. BRM-5058(028) MAJOR BRIDGE PROGRAM CITY OF QUINCY, ADAMS COUNTY C-96-229-07

LIST OF STANDARDS, SEE SHEET 2


MISCELLANEOUS DETAILS


CROSS SECTIONS

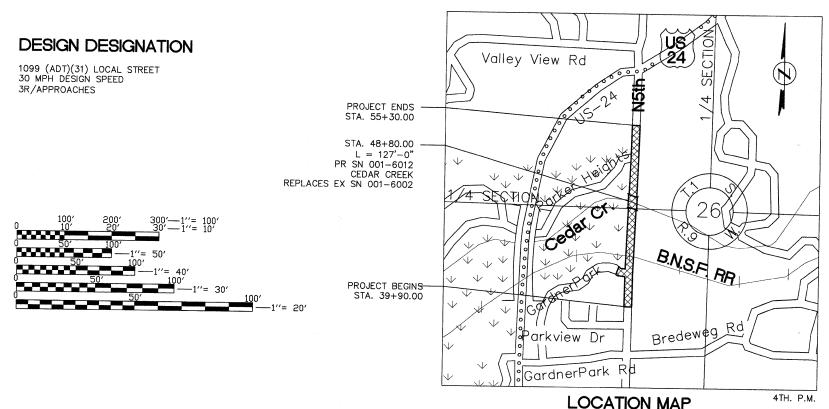


PROJECT DESCRIPTION

  THIS PROJECT INCLUDES THE REMOVAL OF THE EXISTING STRUCTURE AND CONSTRUCTION OF A NEW BRIDGE (127 T B/B ABUTMENTS) WHICH INCLUDES PLACING OF RIPRAP IN THE CHANNEL, CONSTRUCTION OF THE CONCRETE ABUTMENTS, PLACEMENT OF 52" WEB PLATE GIRDERS, POURED CONCRETE DECK, CONCRETE BARRIER WALL, EARTHWORK AND ASSOCIATED WITH THE ROADWAY IMPROVEMENTS...





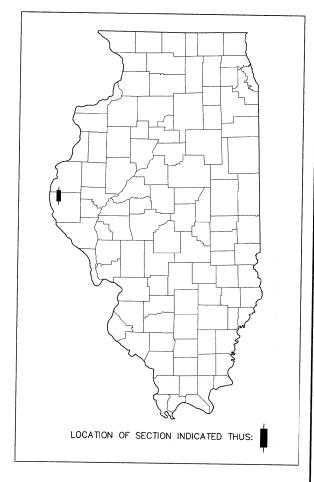

APPROVED	DECEMBER SIL	20 10
	Jeffrey to Sternlung	- 20 <u>10</u>
APPROVED .	DECEMBER STA	20 10
	MAYOR Y	-
PASSED	January 6, 2011	2011
-	DISTRICT SIX ENGINEER OF LOCAL ROADS & STREETS	-
PASSED _	January 6	20 <u>//</u>
-	DISTRICT SIX ENGINEER OF CONSTRUCTION	
Releasing For Bid Based on Limited Review_	January 6, 2011	20 #
	Roger L. Driskell MAP	
	DEPUTY UIRECTOR OF HIGHWAYS, REGION FOUR ENGINEER	
	STATE OF ILLINOIS DEPARTMENT OF TRANSPORTATION	

PSBA
POEPPING, STONE, BACH & ASSOCIATES, INC.
ARCHITECTS ENGINEERS PLANNERS SURVEYORS

100 SOUTH 54TH STREET QUINCY, ILLINOIS PH (217) 223-4605 FAX (217) 223-1546 DESIGN FIRM REGISTRATION NO. 184-000493

PRINTED BY THE AUTHORITY OF THE STATE OF ILLINOIS

JULLIE.
JOINT UTILITY LOCATION INFORMATION FOR EXCAVATION
1-800-892-0123

CONTRACT NO. 93542

GROSS LENGTH OF IMPROVEMENT = 1,540.00 FEET (0.292 MILES) NET LENGTH OF IMPROVEMENT = 1,540.00 FEET (0.292 MILES)

0 400' 80 SCALE: 1" = 400'