

F.A.P. RTE.	SECTION	COUNTY	TOTAL SHEETS	SHEET NO.
67	S(RS-5,TS-7),L	SANGAMON	78	34
STA.		TO STA.		
FED. ROAD DIST. NO.	ILLINOIS	FED. AID PROJECT		


LIGHTING LEGEND

-  400 WATT, HPS LUMINAIRE, 50 FT. MOUNTING HEIGHT, ALUMINUM POLE, 15 FT. DAVIT ARM
-  250 WATT, HPS LUMINAIRE, 45 FT. MOUNTING HEIGHT, ALUMINUM POLE, 15 FT. DAVIT ARM
-  LIGHTING CONTROLLER
-  UNITDUCT, 2 #8 XLP, 1 #8 XLPG, 3/4 IN. DIA., UNLESS NOTED OTHERWISE
-  CONDUIT, AUGERED, 2" DIA. PVC - LENGTH AS SHOWN

NOTES:

1. SEE SHEET #22 FOR PROPOSED SIDEWALK PROFILE.
2. SEE SHEETS #55 THRU #78 FOR PROPOSED SIDEWALK CROSS SECTION

EXIST. CURVE 404
 PI STA. = 130+53.27
 $\Delta = 22^\circ 35' 04''$ (RT)
 $D = 3^\circ 59' 15''$
 $R = 1,436.88'$
 $T = 286.91'$
 $L = 566.38'$
 $E = 28.37'$
 $e = \text{---}$
 $T.R. = \text{---}$
 $S.E. \text{ RUN} = \text{---}$
 $P.C. \text{ STA.} = 127+66.35$
 $P.T. \text{ STA.} = 133+32.73$

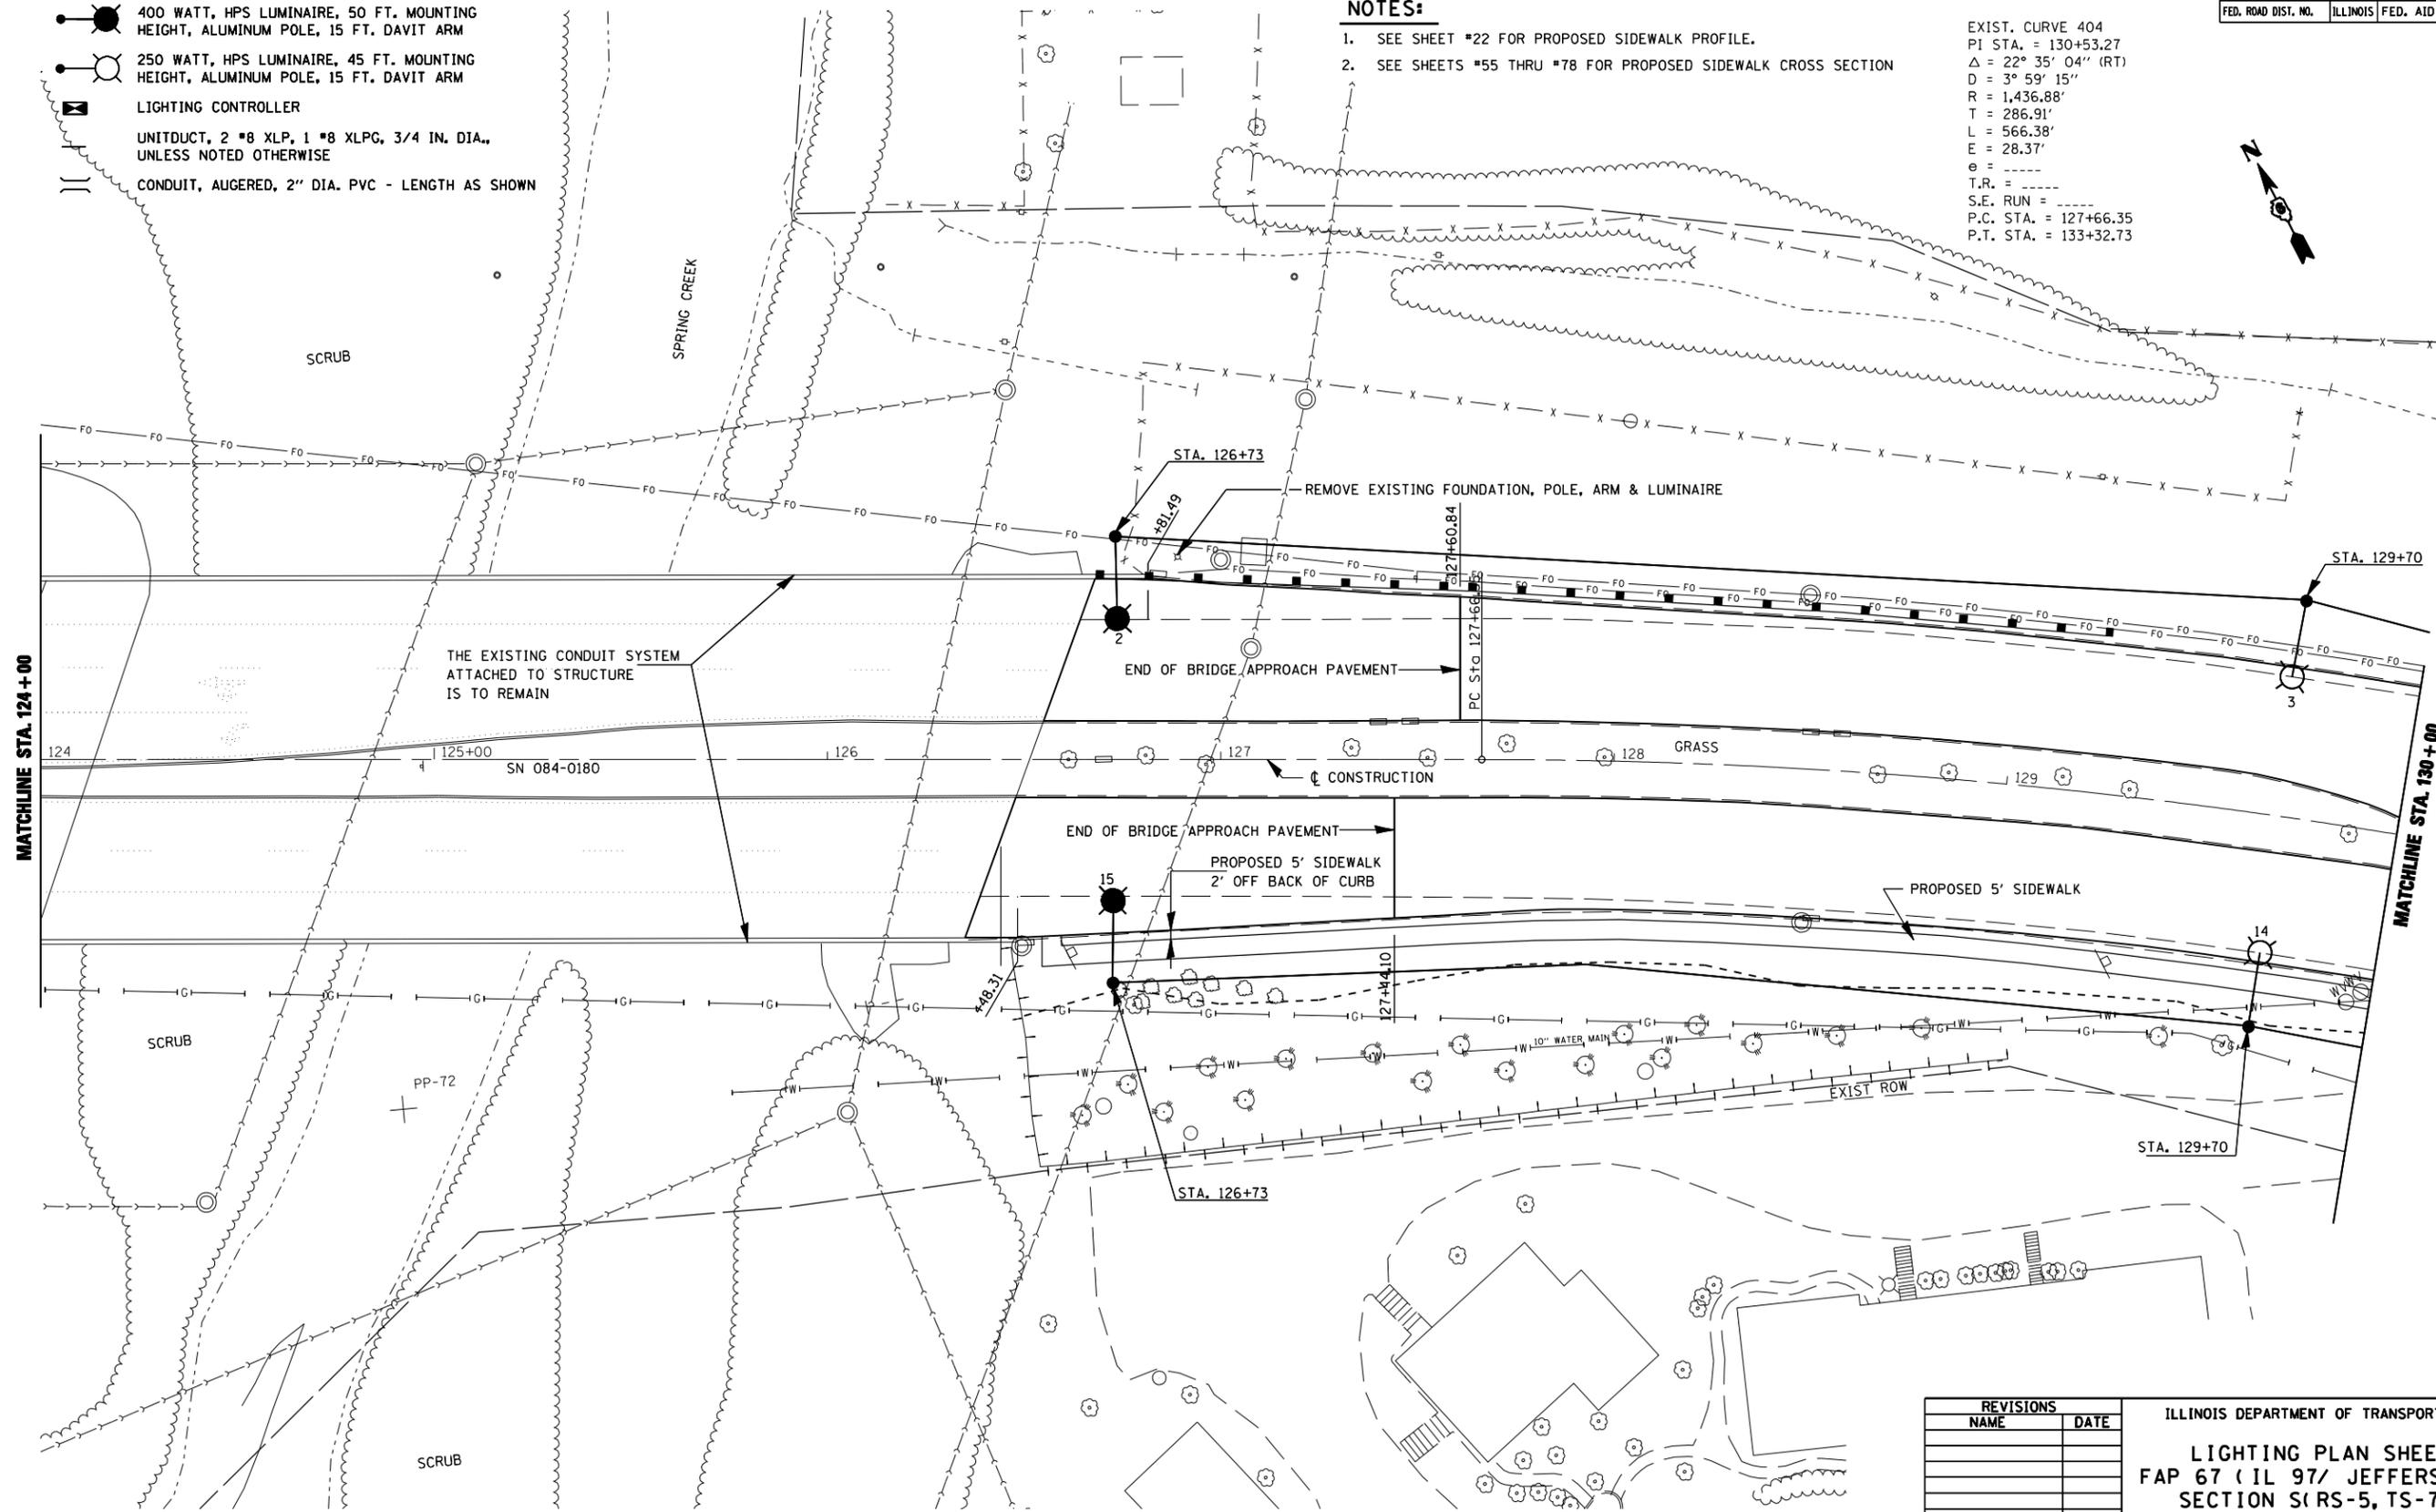

PLOT DATE = #DATE#
 FILE NAME = #FILE#
 USER NAME = #USER#

REVISIONS	
NAME	DATE

ILLINOIS DEPARTMENT OF TRANSPORTATION
LIGHTING PLAN SHEETS
 FAP 67 (IL 97/ JEFFERSON ST)
 SECTION S(RS-5, TS-7), L
 SANGAMON COUNTY

SCALE: VERT. _____
 HORIZ. _____
 DATE _____

DRAWN BY _____
 CHECKED BY _____