
STATE OF ILLINOIS DEPARTMENT OF TRANSPORTATION


ROUTE NO.	SECTION	COUNTY		TOTAL SHEETS	SHEET NO.
c.A.P.	05-00130 -00-BR	WILL		40	11
ED. ROAD	DIST. NO. 7	ILLINOIS	FED. AID PROJECT-		

CONTRACT NO. 83889

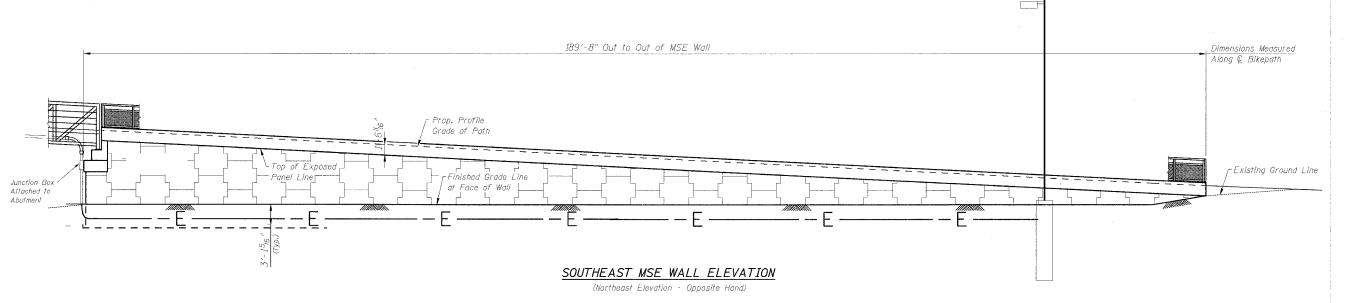

NOTES

- 1. Electrical items are shown not to scale for clarity.
- 2. Fiftings, elbows, LBs, expansion joints and other misc. fittings and brackets are not shown for clarity. All items required to complete the work shall be included.
- 3. All work to conform to Section 800 of IDOT Standard specifications and the latest revision of the NEC.

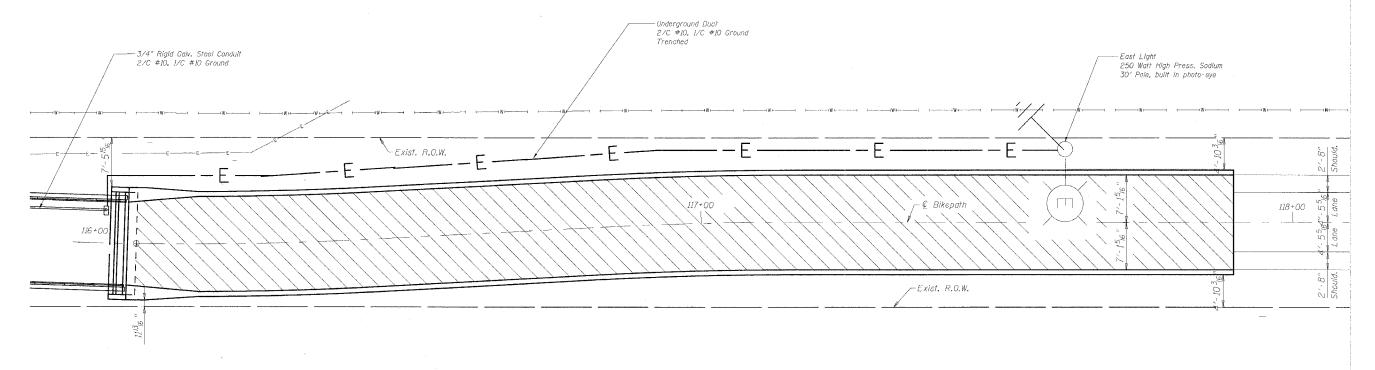

EAST MSE WALL PLAN

NAME DATE

100 South Wacker Drive,
Sulte 500
Chicago, IL 60606
(312) 939-1000

ILLINOIS DEPARTMENT OF TRANSPORTATION EAST MSE PLAN & ELEV ELECTRICAL DETAILS

ROUTE 59 PEDESTRIAN BRIDGE CITY OF NAPERVILLE, WILL COUNTY

RTE. 59 STATION 113+02.46 SCALE: N.T.S. SECTION: 05-00130-00-BR STRUCTURE NO. 099-6002 DATE: 12-8-2006

DESIGNED DAD
CHECKED DL

DRAWN SOI

CHECKED