VILLAGE OF LANSING LANSING, ILLINOIS

CONSTRUCTION PLANS FOR LANSING MUNICIPAL AIRPORT

REHABILITATE AIRFIELD LIGHTING SYSTEM RUNWAY 9/27 AND PARALLEL TAXIWAY

DESIGN INFORMATION

 
GEOMETRIC CRITERIA

AIRPLANE DESIGN GROUP II
AIRCRAFT APPROACH CATEGORY B

LANSING MUNICIPAL AIRPORT

TOWNSHIP: 36 NORT RANGE: 15 EAST 8LOOM TOWNSHIP (SECTION: 8 AND 17)

OPPOSITE GLENWOOD-LANSING
ROAD




FULL SIZE PLANS HAVE BEEN PREPARED USING STANDARD ENGINEERING SCALES. REDUCED SIZED PLANS WILL NOT CONFORM TO STANDARD SCALES. IN MAKING MEASUREMENTS ON REDUCED PLANS, THE ABOVE SCALES MAY BE USED.


CALL J.U.L.I.E. BEFORE EXCAVATING
JOINT UTILITY LOCATION INFORMATION FOR EXCAVATION
1-800-892-0123

ILLINOIS PROJECT: IGQ-3565 A.I.P. PROJECT: 3-17-0121-B25

02 MARCH 2007

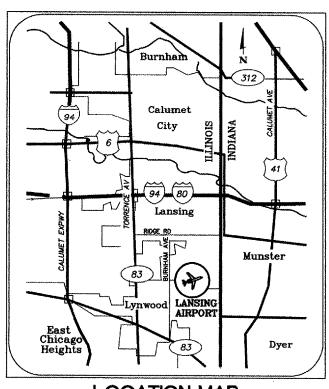



LOCATION MAP

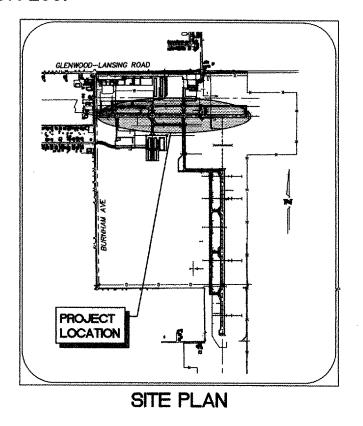


CONTRACT NO. LA036 TOTAL SHEETS = 21

COOK COUNTY

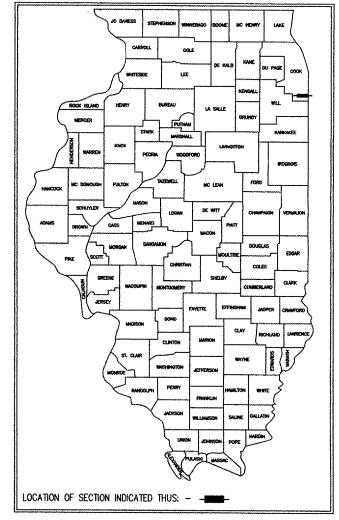

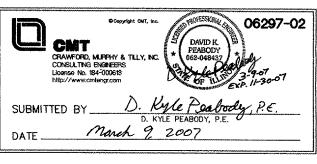

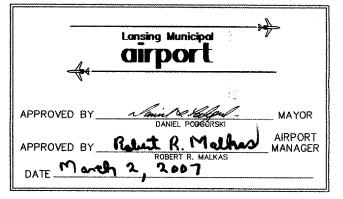

INDEX TO SHEETS					
SHEET NUMBER	SHEET TITLE				
01	COVER SHEET				
02	INDEX TO SHEETS - SUMMARY OF QUANTITIES				
03	SITE PLAN - HORIZONTAL AND VERTICAL CONTROL PLAN				
04	SEQUENCE OF CONSTRUCTION - GENERAL NOTES - CRITICAL POINTS				
05	SEQUENCE OF CONSTRUCTION - PHASE 1				
06	SEQUENCE OF CONSTRUCTION - PHASE 2				
07	SEQUENCE OF CONSTRUCTION - DETAILS				
08	EXISTING CONDITIONS & DEMOLITION - STA. 1+00 TO STA. 12+00				
09	EXISTING CONDITIONS & DEMOLITION - STA. 12+00 TO STA. 26+00				
10	EXISTING CONDITIONS & DEMOLITION - STA. 26+00 TO STA. 40+00				
11	PAVEMENT MARKINGS - RUNWAY 9-27				
12	PAVEMENT MARKINGS - AIRFIELD LETTERS AND SYMBOLS				
13	AIRFIELD LIGHTING PLAN - STA. 1+00 TO STA. 12+00				
14	AIRFIELD LIGHTING PLAN - STA. 12+00 TO STA. 26+00				
15	AIRFIELD LIGHTING PLAN - STA. 26+00 TO STA. 40+00				
16	AIRFIELD LIGHTING PLAN - ELECTRICAL VAULT				
17	AIRFIELD SIGNING PLAN - RUNWAY 9-27				
18	ELECTRICAL DETAILS - AIRFIELD LIGHTING - GENERAL DETAILS				
19	ELECTRICAL DETAILS - AIRFIELD LIGHTING - EDGE LIGHTS				
20	ELECTRICAL DETAILS - AIRFIELD LIGHTING - THRESHOLD LIGHTS				
21	ELECTRICAL DETAILS - AIRFIELD LIGHTING - WIND CONE				

	SUMMARY OF		~~p~~~~	
ITEM NO.	ITEM DESCRIPTION	UNIT	QUANTITY	RECORD
BASE BID				
AR107408	L - 806 WIND CONE - 8' LIGHTED	EACH	1	
AR107900	REMOVE WIND CONE	EACH	1	
AR108108	1/C #8 5 KV UG CABLE	L.F.	2,550	
AR108158	1/C #8 5 KV UG CABLE IN UD	L.F.	17,500	
AR109210	VAULT MODIFICATIONS	L.S.	1	
AR125100	ELEVATED RETROREFLECTIVE MARKER	EACH	9	
AR125410	MITL - STAKE MOUNTED	EACH	107	
AR125415	MITL - BASE MOUNTED	EACH	11	
AR125505	MIRL, STAKE MOUNTED	EACH	21	
AR125510	MIRL, BASE MOUNTED	EACH	12	
AR125540	MI THRESHOLD LIGHT STAKE MTD	EACH	8	
AR125545	MI THRESHOLD LIGHT BASE MTD	EACH	8	
AR125901	REMOVE STAKE MOUNTED LIGHT	EACH	122	
AR125902	REMOVE BASE MOUNTED LIGHT	EACH	28	
AR125986	REFURBISH REILS	PAIR	2	
AR150510	ENGINEER'S FIELD OFFICE	L.S.	1	
AR401910	REMOVE & REPLACE BIT, PAVEMENT	S.Y.	42	
AR620520	PAVEMENT MARKING - WATERBORNE	S.F.	8,400	
AR620525	PAVEMENT MARKING - BLACK BORDER	S.F.	1,195	
AR620900	PAVEMENT MARKING REMOVAL	S.F.	3,600	***************************************
AR800140	2 1/C # 6 XLP-USE, 1/C # 10 GND - 1" UD	L.F.	1,000	T-110
AR800187	THRESHOLD LIGHT BAR	EACH	2	
AR800894	RETROFIT EXIST MITL OR TXY SIGN	EACH	39	***************************************
ADD. ALT. NO.1			***************************************	
AS125442	TAXIWAY GUIDANCE SIGN, 2 CHARACTE	EACH	1	
AS125443	TAXIWAY GUIDANCE SIGN, 3 CHARACTE	EACH	1	· · · · · · · · · · · · · · · · · · ·
AS125445	TAXIWAY GUIDANCE SIGN, 5 CHARACTE	EACH	2	***************************************
AS125904	REMOVE TAXIWAY GUIDANCE SIGN	EACH	4	
ADD. ALT. NO.2				······································
AT125442	TAXIWAY GUIDANCE SIGN, 2 CHARACTE	EACH	10	

IL. CONTRACT: LA036

IL. LETTING ITEM: 2A

IL. PROJECT: IGQ-3565 A.I.P. PROJECT: 3-17-0121-B25

SURVEY BOOK # BOOK #

REVISIONS					
NUMBER	BY	DATE			

THIS BAR IS EQUAL TO 2" AT FULL SCALE (34X22).

REHABILITATE AIRFIELD LIGHTING SYSTEM INDEX TO SHEETS SUMMARY OF QUANTITIES VILLAGE OF LANSING LANSING MUNICIPAL AIRPORT LANSING, ILLINOIS



DESIGN BY: JWD DRAWN BY: JWD CHECKED BY: DKP APPROVED BY: DATE: 02 MARCH 2007 JOB No: 06297-02

G-02

SHEET 02 OF 21 SHEETS

HORIZONTAL/VERTICAL CONTROL STATION/OFFSET ELEVATION **NORTHING EASTING** DESCRIPTION 311+98.00 @ TAXIWAY G2 1775650.38 719616.74 INTERSECTION CENTERLINE TAXIWAY G2 AND CENTERLINE TAXIWAY G3 314+48.10 @ TAXIWAY G2 1775900.49 719615.05 INTERSECTION CENTERLINE TAXIWAY G2 AND CENTERLINE RUNWAY 9/27 316+98.10 @ TAXIWAY G2 1776150,48 719613.35 INTERSECTION CENTERLINE TAXIWAY G2 AND CENTERLINE TAXIWAY A 318+54.10 @ TAXIWAY G2 1776306.46 719612.18 INTERSECTION CENTERLINE TAXIWAY G2 AND APRON BASELINE 5 321+26.10 £ TAXIWAY G2 1776578.44 719610.29 INTERSECTION CENTERLINE TAXIWAY G2 AND ENTRANCE ROAD BASELINE 318+54.10, 300' RT, @ TAXIWAY G2 719912.17 1776308.55 EDGE OF APRON 502+28.16, & ENTRANCE RD. 1776580.67 719938.45 ENTRANCE ROAD BASELINE 719937.64 503+44.19, & ENTRANCE RD. 1776696.69 INTERSECTION ENTRANCE ROAD BASELINE AND BORROW SITE BASELINE 504+14.16, & ENTRANCE RD. 1776766.66 719937.16 ENTRANCE ROAD BASELINE 507+66.32, & ENTRANCE RD. 720057.13 1776995.73 INTERSECTION ENTRANCE ROAD BASELINE AND CENTERLINE GLENWOOD-LANSING ROAD 505+38.08, & ENTRANCE RD. 1776767.53 720061.07 ENTRANCE ROAD BASELINE 12 18+50, & BORROW SITE 1776703.13 720882.47 END OF BORROW SITE BASELINE 13 507+72.05, 99.53' LT, & ENTRANCE RD. 1776999.75 719957.51 PK NAIL ON GLENWOOD-LANSING ROAD MEDIAN 14 325+30.13, 498.64 LT, C TAXIWAY G2 1776979.01 719108.85 PK NAIL ON GLENWOOD-LANSING ROAD MEDIAN 3+10.61, 215.31' RT, @ RUNWAY 9/27 BM1 1775672.09 613,53 717734.60 AZ MARKER "LANSPORT" (ROD IN CAN) (#202) Вм2 23+37.02, 209.83' RT, Q RUNWAY 9/27 613.56 1775691.67 719760.92 MARKER "LANSPORT 1990" (ROD IN CAN) (#201) 37+49.70, 195.54' RT, C RUNWAY 9/27 1775715.79 613.69 721173.47 GPS IGOA MONUMENT (#205) BM4 146+22.30, 582.00' RT, @ RUNWAY 18/36 614.13 1775185.59 721169.44 CHISELED "X" ON CONCRETE BOX CULVERT NEW AIRPORT IMPROVEMENTS **LEGEND** EXISTING BUILDING EXISTING PAVEMENT PROPOSED BORROW SITE TAXIWAY C # BENCHMARK/CONTROL POINT AIRPORT PROPERTY LINE FUTURE/PROPOSED HANGAR (BY OTHERS) TAXIWAY G2

IL. CONTRACT: LA036

IL. LETTING ITEM: 2A

IL. PROJECT: **IGQ-3565**AJ.P. PROJECT: **3-17-0121-B25**

SURVEY BOOK # BOOK #

REVISIONS

NUMBER BY DATE

THIS BAR IS EQUAL TO 2" AT FULL SCALE (34X22).

VILLAGE OF LANSING LANSING MUNICIPAL AIRPORT LANSING, ILLINOIS

REHABILITATE AIRFIELD LIGHTING SYSTEM
SITE PLAN
HORIZONTAL AND VERTICAL CONTROL PLAN
LANSING MUNICIPAL AIRPORT

CRAWFORD, MARPHY & TILL
CRAWFORD, MARPHY & TILL
CRAWFORD, MARPHY & TILL
CRAWFORD, MARPHY & TILL
CONSULTING ENGRERS
LIGHTORY
Lansing Municipal
CIFFORT

DESIGN BY: LAO

DRAWN BY: JWD

CHECKED BY: DKP

APPROVED BY: ----
DATE: 02 MARCH 2007

G-03

JOB No: 06297-02

EFT 07 OF 04 CU

: Thursday, March

GENERAL NOTES

- THE SUGGESTED SEQUENCE OF CONSTRUCTION SHOWN IS INTENDED TO ALLOW FOR THE ORDERLY CONSTRUCTION OF THE PROPOSED IMPROVEMENTS WHILE MAINTAINING AIRCRAFT ACCESS AT ALL TIMES. THE PHASING SHOWN IS A SUGGESTED SEQUENCE OF CONSTRUCTION ONLY, THIS SEQUENCE MAY BE MODIFIED; HOWEVER, ALTERNATE STAGING PLANS MUST MAINTAIN AIRPORT OPERATIONS TO THE SATISFACTION OF THE AIRPORT MANAGER AND RESIDENT ENGINEER AND BE APPROVED BY THE DIVISION OF AFRONALITICS AND FEDERAL AVIATION ADMINISTRATION
- ALL OPERATIONS SHALL BE IN CONFORMANCE WITH AC 150/5370-2E (LATEST EDITION) SAFETY DURING
- CONTRACTOR'S EQUIPMENT SHALL BE STORED IN THE EQUIPMENT AND MATERIAL STORAGE AREA
- THE AIRPORT MANAGER IN CONSULTATION WITH THE RESIDENT ENGINEER SHALL HAVE FINAL SAY IN THE APPROVAL OF THE CONSTRUCTION OPERATING SEQUENCE AS IT RELATES TO PEDESTRIAN. VEHICULAR AND AIRCRAFT SAFETY.
- 5. ALL EXISTING PAVEMENTS, DRIVES OR ANY OTHER AREAS USED AS A HAUL ROAD OR STORAGE AREA BY THE CONTRACTOR SHALL BE RESTORED IN KIND TO THEIR PRE-CONSTRUCTION CONDITION OR TO THE SATISFACTION OF THE RESIDENT ENGINEER AND AIRPORT MANAGER, THE COST OF MAINTAINING, REPAIRING OR CONSTRUCTING THESE PAVEMENTS AND AREAS SHALL BE INCIDENTAL TO THE CONTRACT. EXISTING AREAS OUTSIDE THE PROJECT LIMITS WHICH ARE DISTURBED BY THE CONTRACTOR'S OPERATIONS SHALL BE RESTORED BY HIM AT HIS EXPENSE TO THE SATISFACTION OF THE RESIDENT ENGINEER AND THE AIRPORT MANAGER
- THE CONTRACTOR SHALL KEEP ALL TRUCKS, EQUIPMENT AND MATERIALS OFF OF THE EXISTING TAXIWAYS, APRONS AND RUNWAYS OUTSIDE OF THE PROJECT LIMITS EXCEPT AS SHOWN OR WITH THE PRIOR PERMISSION OF THE ENGINEER
- WORK PERFORMED BY THE CONTRACTOR OUTSIDE OF DAYLIGHT HOURS SHALL BE DONE UNDER SUFFICIENT ARTIFICIAL LIGHTING TO ALLOW FOR PROPER CONSTRUCTION METHODS AND INSPECTIONS, LIGHT SHALL CONSIST OF MOVABLE POLE MOUNTED FLOODLIGHTS AND/OR SPOTLIGHTS OF SUFFICIENT NUMBER TO ILLUMINATE THE WORK AREA. VEHICLE HEADLIGHTS WILL BE ALLOWED ONLY IN ADDITION TO OTHER LIGHTS MENTIONED ABOVE. LIGHTING SHALL BE AS APPROVED BY THE ENGINEER AND SHALL NOT BE USED IF THEY AFFECT FLIGHT SAFETY. CONTRACTOR'S WORK HOURS SHALL BE IN ACCORDANCE WITH LOCAL ORDINANCES.
- 8. THE CONTRACTOR SHALL PROVIDE PORTABLE FLOOD LIGHTING FOR NIGHTTIME CONSTRUCTION. SUFFICIENT UNITS SHALL BE PROVIDED SO THAT WORK AREAS ARE ILLUMINATED TO A LEVEL OF FIVE HORIZONTAL FOOT CANDLES. THE LIGHTING LEVELS SHALL BE CALCULATED AND MEASURED IN ACCORDANCE WITH THE CURRENT STANDARDS OF THE ILLUMINATION ENGINEERING SOCIETY, LIGHTS SHALL BE POSITIONED SO AS NOT TO INTERFERE WITH AIRPORT OPERATIONS.
- 9. THE CONTRACTOR WILL BE REQUIRED TO HAVE A SWEEPER AVAILABLE FOR USE AT ALL TIMES. WHEN ACTIVE AIRPIELD PAVEMENTS ARE LITILIZED AS HALL ROADS BY THE CONTRACTOR, MATERIAL TRACKED ON TO THE PAVEMENT SHALL BE CONTINUALLY REMOVED WITH SAID SWEEPER. THIS SWEEPING SHALL NOT BE PAID FOR SEPERATELY BUT SHALL BE CONSIDERED INCIDENTAL TO THE
- MATERIALS REMOVED FROM THE PROJECT WILL BE DISPOSED OF OFF AIRPORT PROPERTY, UNLESS NOTED OTHERWISE.
- TRAFFIC CONTROL: PAYMENT FOR TRAFFIC CONTROL INCLUDING, BUT NOT LIMITED TO BARRICADES. SIGNING, RUNWAY CLOSED MARKERS, AIR OPERATIONS AREA (A.O.A.) LATHE AND RIBBON, ETC. SHALL NOT BE PAID SEPARATELY, BUT SHALL BE CONSIDERED INCIDENTAL TO THE CONTRACT. BARRICADES AT 10-FOOT CENTERS WITH ONE ORANGE FLAG (24" x 24") BETWEEN EACH SET OF BARRICADES SHALL BE PLACED AT THE LOCATIONS SHOWN ON THE PLANS OR AS DIRECTED BY THE ENGINEER BARRICADES SHALL BE WEIGHTED TO PREVENT BLOWING OVER. BARRICADES SHALL HAVE A FLASHING RED LIGHT AND CONFORM TO IDOT STANDARD 702001, TYPE II. BARRICADE INSTALLATION WILL BE REQUIRED PRIOR TO ACCESS TO THE A.O.A. BY CONTRACTOR'S WORKERS, EQUIPMENT OR MATERIAL, SIGNS SHALL BE PLACED AT EACH TAXIWAY/RUNWAY CLOSURE LOCATION AND SHALL BE ATTACHED TO THE BARRICADES, EACH BARRICADE LOCATION SHALL CONSIST OF ONE "DO NOT ENTER" SIGN AND ONE "AIRCRAFT MOVEMENT AREA" SIGN, SIGNS SHALL BE CONSIDERED INCIDENTAL
- 12. THE CONTRACTOR SHALL CONTACT THE AIRPORT MANAGER FIVE (5) WORKING DAYS IN ADVANCE OF THE START OF CONSTRUCTION SO THAT THE APPROPRIATE NOTAMS MAY BE ISSUED
- 13. THE CONTRACTOR SHALL BE RESPONSIBLE FOR KEEPING ALL CONSTRUCTION ACCESS GATES CLOSED DURING NON WORKING HOURS. THE CONTRACTOR SHALL PROVIDE A SIGN AT THE ACCESS GATE SAYING "AUTHORIZED PERSONNEL ONLY". THE CONTRACTOR SHALL CLOSE AND LOCK THE ACCESS GATE LIPON LEAVING THE SITE THROUGHOUT THE DURATION OF THE CONTRACT, ANY DAMAGES TO THE ACCESS ROAD, ACCESS GATE OR FENCING ADJACENT TO THE PROJECT SHALL BE REPAIRED BY THE CONTRACTOR TO THE SATISFACTION OF THE RESIDENT ENGINEER. ALL COST RELATING TO CONTRACTOR'S ACCESS AND SECURITY SHALL BE THE RESPONSIBILITY OF THE CONTRACTOR.
- 14. CONTRACTOR WILL BE REQUIRED TO PUT AIRPORT FLAGS AND HAVE BEACON LIGHTS ON ALL EQUIPMENT AT ALL TIMES DURING CONSTRUCTION. SEE FLAG DETAIL,
- 15. IN THE CASE OF AN EMERGENCY CONTRACTOR SHALL NOTIFY AIRPORT MANAGER AND THE ENGINEER IMMEDIATELY.
- 16. DURING ADVERSE WEATHER, THE CONTRACTOR SHALL MAKE PROVISIONS FOR ACCESS TO THE WORK AT NO ADDITIONAL COST TO THE CONTRACT. NO EXTENSION OF CONTRACT TIME WILL BE CONSIDERED FOR DELAYS DUE TO LACK OF ADEQUATE ACCESS TO THE WORK
- 17. THE TALLEST PIECE OF CONSTRUCTION EQUIPMENT IS ANTICIPATED TO BE AN ASPHALT/STONE TRUCK WHICH HAS AN ANTICIPATED MAXIMUM HEIGHT OF TWENTY (20) FEET IN A DUMP POSITION.
- 18. IF RUNWAY NUMERALS ARE PRESENT DURING CONSTRUCTION THEN CONTRACTOR SHALL PLACE CLOSED RUNWAY MARKER OVER NUMERALS AS DETAILED, OTHERWISE PLACE RUNWAY CLOSED MARKER IN TURE AT ENDS OF RUNWAY AS DETAILED.
- LANSING MUNICIPAL AIRPORT WILL BE IN OPERATION DURING THE CONSTRUCTION OF THIS PROJECT. COORDINATION OF WORK WITH THE AIRPORT IS MANDATORY SO AS TO MINIMIZE IMPACTS ON AIRPORT OPERATIONS.

- 20. APPROXIMATE LOCATION OF HAUL ROUTES ON THE AIRPORT SITE IS SHOWN ON THE GENERAL PROJECT LAYOUT AND THE PHASING PLANS. IT SHALL BE THE CONTRACTOR'S RESPONSIBILITY TO COORDINATE OFF-SITE HAUL ROUTES (STATE HIGHWAYS, COUNTY ROADS OR CITY STREETS) WITH THE APROPRIATE OWNER WHO HAS JURISDICTION OVER THE AFFECTED ROUTE, ON-SITE ROADS USED AS HAUL ROUTES SHALL BE MAINTAINED BY THE CONTRACTOR AND SHALL BE RESTORED AT THE CONTRACTOR'S EXPENSE TO THEIR ORIGINAL CONDITION UPON COMPLETION OF BEING USED AS A HAUL ROUTE. THE BEFORE AND AFTER CONDITION OF ON-SITE HAUL ROUTES SHALL BE JOINTLY INSPECTED AND DETERMINED BY THE CONTRACTOR AND THE ENGINEER, FENCING, DRAINAGE, GRADING AND OTHER MISCELLANEOUS CONSTRUCTION REQUIRED TO CONSTRUCT TEMPORARY HAUL ROUTES OR ACCESS POINTS ON THE AIRPORT WILL BE THE CONTRACTOR'S TOTAL RESPONSIBILITY AND SHALL BE APPROVED BY THE ENGINEER PRIOR TO THE WORK. ALL ON-SITE ACCESS ROADS TO AIRPORT FACILITIES SHALL REMAIN OPEN AND MAINTAINED AT ALL TIMES.
- 21. MOBILIZATION/EQUIPMENT STORAGE AREA WILL BE MADE AVAILABLE FOR CONTRACTOR'S MOBILIZATION AND STORAGE AS SHOWN ON THE PLANS. THIS AREA SHALL BE RESTORED TO THE ORIGINAL CONDITION UPON COMPLETION OF THE PROJECT AT THE CONTRACTOR'S EXPENSE.
- 22. LOCATION OF KNOWN EXISTING AIRPORT UNDERGROUND CABLES ARE SHOWN ON THE PLANS AND MUST BE VERIFIED BY THE CONTRACTOR. REPAIR OF DAMAGED CABLE MUST BE STARTED IMMEDIATELY AND CONTINUED UNTIL COMPLETED ALL SUCH REPAIRS SHALL BE IN ACCORDANCE WITH THE SPECIFICATIONS, OR AS DIRECTED BY THE OWNER OF THE CABLE, AND SHALL BE AT THE CONTRACTOR'S EXPENSE. IF FAA CABLES ARE DAMAGED, REPAIRS SHALL BE DONE FROM POINT TO POINT IN ACCORDANCE WITH FAA REQUIREMENTS AND IN THE PRESENCE OF A FAA REPRESENTATIVE. THE OWNER MAY ELECT TO HAVE THE REPAIR PERRFORMED BY OTHERS IN WHICH CASE THE CONTRACTOR SHALL BE RESPONSIBLE FOR PAYING THE INCURRED COSTS OF REPAIRS.
- 23. COORDINATION MEETINGS THE CONTRACTOR SHALL CONDUCT WEEKLY COORDINATION MEETINGS TO DISCUSS WORK AREAS AND SCHEDULING, ETC. WITH THE ENGINEER, AIRPORT OPERATIONS, FAA, AND OTHER APPROPRIATE OFFICIALS. MINUTES FROM THE WEEKLY MEETINGS SHALL BE PREPARED BY THE CONTRACTOR, FURNISHED TO ALL ATTENDEES PRIOR TO THE SUBSEQUENT MEETING, AND KEPT ON FILE AT THE FIELD OFFICE. THE COORDINATION MEETING COSTS SHALL BE CONSIDERED INCIDENTAL TO THE PROJECT.
- 24. THE CONTRACTOR SHALL PROVIDE THE PHONE NUMBERS OF THREE PERSONNEL, INCLUDING THE PROJECT SUPERINTENDENT, WHO MAY BE CONTACTED IN AN EMERGENCY. PERSONNEL SHALL BE ON CALL 24 HOURS PER DAY FOR MAINTAINING AIRPORT HAZARD LIGHTING AND BARRICADES
- 25. DRAINAGE MODIFICATIONS SHALL BE SEQUENCED TO PROVIDE POSITIVE DRAINAGE AT ALL TIMES AT NO ADDITIONAL COST TO THE CONTRACT. EXISTING LANSING DRAINAGE FLOWS SHALL BE MAINTAINED.
- 26. VEHICLES AND EQUIPMENT SHALL NOT BE ALLOWED WITHIN 65' FROM ACTIVE TAXIWAYS AND 125' FROM ACTIVE RUNWAYS UNLESS OTHERWISE APPROVED BY THE AIRPORT MANAGER.
- 27. CONTRACTOR SHALL STORE EQUIPMENT AND MATERIALS IN SUCH A MANNER AS NOT TO VIOLATE EDERAL AVIATION ADMINISTRATION PART 77 SURFACES OR RUNWAY AND TAXIWAY SAFETY AREAS.
- 28. ALL EXISTING TAXIWAY AND RUNWAY AIRFIELD LIGHTING CIRCUITS, FAA CABLES AND OTHER ELECTRICAL CABLES SHALL REMAIN IN SERVICE AT ALL TIMES. ALL EXISTING LIGHTING AND VAULT FOLIPMENT SHALL REMAIN IN SERVICE LINTIL PROPOSED IMPROVEMENTS ARE INSTALLED AND OPERATIONAL, UNLESS OTHERWISE APPROVED BY THE ENGINEER, ANY CABLES DAMAGED BY THE CONTRACTOR SHALL BE IMMEDIATELY REPAIRED AT HIS EXPENSE
- 29. COORDINATION BY THE CONTRACTOR WITH THE EXISTING UTILITIES SHALL BE COMPLETED BEFORE CONSTRUCTION IS STARTED. CONTRACTOR IS REFERRED TO SECTION 50-17 OF THE SPECIAL PROVISIONS FOR SPECIFIC REQUIREMENTS. THE LOCATION OF UNDERGROUND UTILITIES AS INDICATED ON THE PLANS HAS BEEN OBTAINED FROM EXISTING RECORDS, NEITHER THE OWNER NOR THE DESIGN ENGINEER ASSUME ANY RESPONSIBILITY WHATEVER IN RESPECT TO THE ACCURACY COMPLETENESS OR SUFFICIENCY OF THE INFORMATION, THERE IS NO GUARANTEE, EITHER EXPRESSED OR IMPLIED THAT THE LOCATIONS, SIZE AND TYPE MATERIAL OF EXISTING UNDERGROUND UTILITIES AS INDICATED ARE REPRESENTATIVE OF THOSE TO BE ENCOUNTERED DURING CONSTRUCTION, IT SHALL BE THE CONTRACTOR'S RESPONSIBILITY TO DETERMINE THE ACTUAL LOCATION OF ALL SUCH FACILITIES, INCLUDING SERVICE CONNECTIONS TO UNDERGROUND UTILITIES. PRIOR TO CONSTRUCTION, THE CONTRACTOR SHALL NOTIFY THE UTILITY COMPANY OF HIS OPERATIONAL PLANS. THE CONTRACTOR SHALL MAKE ARRANGEMENTS FOR DETAILED INFORMATION AND ASSISTANCE IN LOCATING UTILITIES. IN THE EVENT AN UNEXPECTED UTILITY INTERFERENCE IS ENCOUNTERED DURING CONSTRUCTION, THE CONTRACTOR SHALL IMMEDIATELY NOTIFY THE UTILITY COMPANY, THE RESIDENT ENGINEER AND THE AIRPORT DIRECTOR. ANY SUCH MAINS AND/OR SERVICES DISTURBED BY THE CONTRACTOR'S OPERATIONS SHALL BE RESTORED IMMEDIATELY AT HIS EXPENSE TO THE SATISFACTION OF THE RESIDENT ENGINEER AND AIRPORT MANAGER
- 30. ALL AIRFIELD LIGHTING AND LIGHTING GUIDANCE SYSTEMS (NAVAIDS) LOCATED WITHIN AND IMMEDIATELY ADJACENT TO THE CONTRACTORS WORK ZONE SHALL BE CHECKED FOR OPERATIONAL CONDITION PRIOR TO THE DEPARTURE FROM THE AIRPORT WITH THE AIRPORT MAINTENANCE, ANY DEFECIENCIES IN THESE SYSTEMS DUE TO THE ACTS OF CONTRACTOR OR HIS SUBCONTRACTORS, SUPPLIERS OR CONSULTANTS SHALL BE REPAIRED IMMEDIATELY.

CONTRACTOR CROSSING RUNWAY AND TAXIWAY AIR OPERATIONS AREA (A.O.A.)

- A. ANYTIME THE CONTRACTOR IS REQUIRED TO UTILIZE OR CROSS ACTIVE AIRFIELD PAVEMENTS FOR ACCESS TO AND FROM THE WORK ZONE, A FULL TIME CROSSING GUARD IN RADIO CONTACT WITH THE AIR TRAFFIC SHALL BE FURNISHED BY THE CONTRACTOR FOR MOVEMENTS OF VEHICLES OR EQUIPMENT TO AND FROM THE WORK ZONE. THE RADIO OPERATOR SHALL BE FAMILIAR WITH AIRPORT GROUND CONTROL PROCEDURES AND DEMONSTRATE KNOWLEDGE OF SAME TO THE AIRPORT. THE AIRPORT RESERVES THE RIGHT TO APPROVE THE CROSSING GUARDS. THE CONTRACTOR SHALL PROVIDE THEIR OWN RADIOS. THIS COST SHALL BE CONSIDERED INCIDENTAL TO THE CONTRACT. THE CONTRACT SHALL BE RESPONSIBLE FOR PAYMENT OF MUNICIPAL FINES (\$500 PER OCCURENCE) DUE TO AIRFIELD INCURSIONS BY HIS EMPLOYEES, SUBCONTRACTORS, SUPPLIERS, CONSULTANTS AND/OR AGENTS.
- B. ANY PAVEMENT DAMAGED BY CONTRACTOR'S OPERATIONS SHALL BE REPAIRED MMEDIATELY BY HIM TO THE SATISFACTION OF THE RESIDENT ENGINEER AND AIRPORT MANAGER AT NO ADDITIONAL COST TO THE OWNER. PAVEMENT SHALL BE CONTINUALLY SWEPT TO PROVIDE DEBRIS FREE SURFACE DURING ALL HAUL ROAD OPERATIONS. THIS COST SHALL NOT BE PAID SEPERATELY BUT SHALL BE CONSIDERED INCIDENTAL TO THE
- C. WORK WITHIN THE A.O.A. SHALL BE EXPEDITED. ANY DROP OFF SHALL BE ADEQUATELY LIGHTED. SIGNED AND BARRICADED. NO MATERIAL SHALL BE STOCKPILED WITHIN THE A.O.A. SHOULD IT BE NECESSARY FOR THE CONTRACTOR TO TEMPORARILY RELOCATE EQUIPMENT TO ALLOW AIRCRAFT TO PASS, THEY SHALL DO SO AT NO EXTRA COST TO THE PROJECT. THE CONTRACTOR SHALL NOTIFY THE RESIDENT ENGINEER AND AIRPORT MANAGER TWO (2) WORKING DAYS IN ADVANCE OF ANY PLANNED CONSTRUCTION WITHIN

DESIGN AIRCRAFT APPROACH CATEGORY: B DESIGN AIRPORT GROUP: II

> MAXIMUM ANTICIPATED HEIGHT OF CONSTRUCTION FOUIPMENT: 20'

POINT "A"

NEAREST POINT ON CONSTRUCTION SITE TO ACTIVE RUNWAY 18/36 OFFSET FROM CENTERLINE EXTENDED LATITUDE: 41'32'22.32"N (NAD 83) LONGITUDE: 87'31'39.59"W (NAD 83) EXISTING ELEVATION: 610.65

POINT "B" NEAREST POINT ON CONSTRUCTION SITE TO ACTIVE
RUNWAY 18/36 OFFSET FROM CENTERLINE EXTENDED
LATITUDE: 41*32*24.79*N (NAD 83)
LONGITUDE: 87*31*39.58*W (NAD 83)
EXISTING ELEVATION: 610.88

POINT "C" NEAREST POINT ON CONSTRUCTION SITE TO ACTIVE RUNWAY 9/27

LATITUDE: 41°32'24.78"N (NAD 83) LONGITUDE: 87°31'32.16"W (NAD 83) EXISTING ELEVATION: 616.55

NEAREST POINT ON CONSTRUCTION SITE TO ACTIVE

LATITUDE: 41'32'24.85"N (NAD 83) LONGITUDE: 87'32'14.64"W (NAD 83) EXISTING ELEVATION: 614.00

LIMITATIONS ON CONSTRUCTION WITHIN AIRPORT OPERATIONS AREA (A.O.A.)

RUNWAYS

ANY WORK WITHIN 125' OF THE CENTERLINE OF AN ACTIVE RUNWAY SHALL EITHER BE DONE ON WEEKENDS, OFF-PEAK DAYTIME OR NIGHTIME HOURS, LOCAL TIME AS SHOWN ON THE SEQUENCE OF CONSTRUCTION PLAN SHEETS. ON ANY DAY WHEN CONSTRUCTION IS WITHIN 125' OF THE CENTERLINE OF THE RUNWAY THE RUNWAY SHALL BE CLOSED, THE CONTRACTOR, SHALL NOTICE THE RESIDENT ENGINEER AND AIRPORT MANAGER TWO (2) WORKING DAYS IN ADVANCE OF ANY PLANNED CONSTRUCTION WITHIN THESE LIMITS.

STEEL PLATES IF NECCESSARY SHALL BE FURNISHED AND INSTALLED BY THE CONTRACTOR TO COVER ANY OPEN TRENCHES OR EXCAVATION WITHIN THE A.O.A. IF DURING RUNWAY CLOSURE AN EMERGENCY IS DECLARED. THE CONTRACTOR SHALL IMMEDIATELY CLEAR THE RUNWAY OF ALL VEHICLES, MEN AND EQUIPMENT

TAXIWAYS / TAXILANES / APRONS:

CONSTRUCTION WILL BE ALLOWED UP TO THE EDGE OF PAVEMENTS WITHOUT CLOSURE ON A LIMITED BASIS. WORK WITHIN THE A.O.A. SHALL BE EXPEDITED. ANY DROP OFF SHALL BE ADEQUATELY LIGHTED, SIGNED AND BARRICADED. NO MATERIAL SHALL BE STOCKPILED WITHIN THE A.O.A. SHOULD IT BE NECESSARY FOR THE CONTRACTOR TO TEMPORARILY RELOCATE EQUIPMENT TO ALLOW AIRCRAFT TO PASS. THEY SHALL DO SO AT NO EXTRA COST TO THE PROJECT. THE CONTRACTOR SHALL NOTIFY THE RESIDENT ENGINEER AND AIRPORT MANAGER TWO (2) WORKING DAYS IN ADVANCE OF ANY PLANNED CONSTRUCTION WITHIN THESE LIMITS.

 
NOTE - ALL PHASES

ALL EXISTING TAXIWAY AND RUNWAY AIRFIELD LIGHTING CIRCUITS, FAA CABLES AND OTHER AIRPORT ELECTRICAL CABLES SHALL REMAIN IN SERVICE UNTIL REPLACED AS ACCEPTABLE TO THE RESIDENT ENGINEER. ALL TEMPORARY CABLING AND SPLICING NECESSARY TO KEEP THE CIRCUITS IN OPERATION SHALL BE CONSIDERED INCIDENTAL TO CONTRACT.

IL. CONTRACT: LA036 IL. LETTING ITEM: 2A IL. PROJECT: IGQ-3565

A.I.P. PROJECT: 3-17-0121-B25

SURVEY BOOK # BOOK #



THIS BAR IS EQUAL TO AT FULL SCALE (34X22).

VILLAGE OF LANSING LANSING MUNICIPAL AIRPORT LANSING, ILLINOIS


REHABILITATE AIRFIELD LIGHTING SYSTEM
SEQUENCE OF CONSTRUCTION
GENERAL NOTES
CRITICAL POINTS


MURPHY & ENGINEERS Corsing Municipal Colors CRAWFORD, CONSULTING DESIGN BY JWD


RAWN RY JWD CHECKED BY DKP APPROVED BY: DATE: 02 MARCH 2007 JOB No: 06297-02


G-04

SHEET 04 OF 21 SHEETS

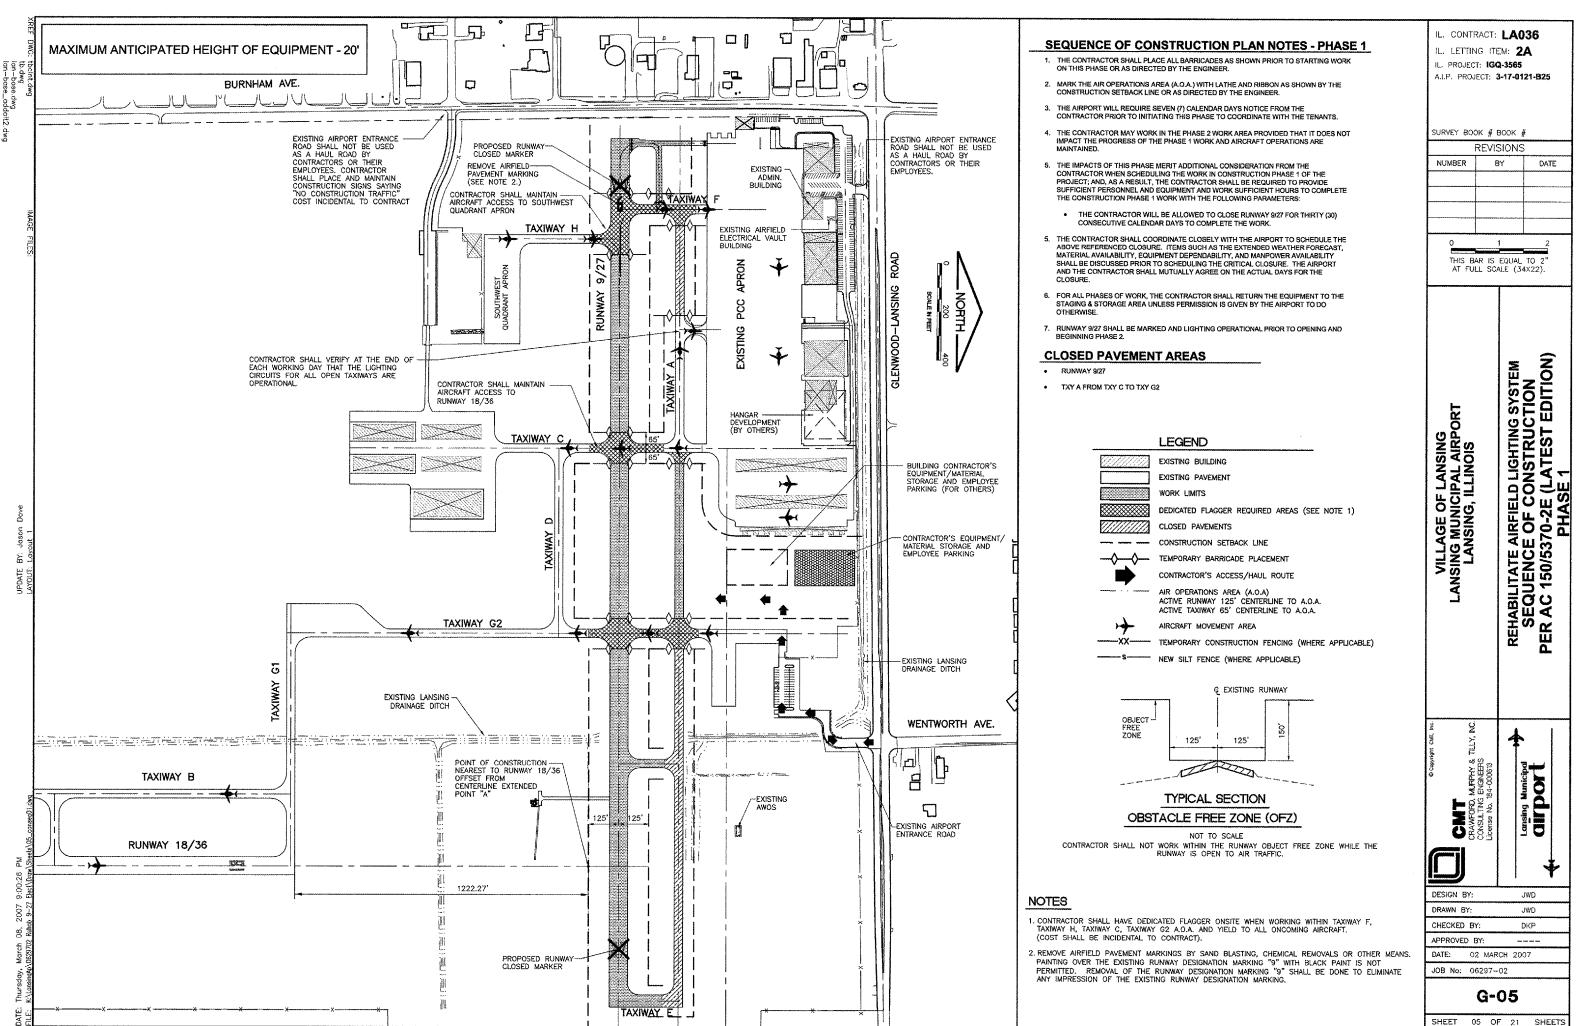

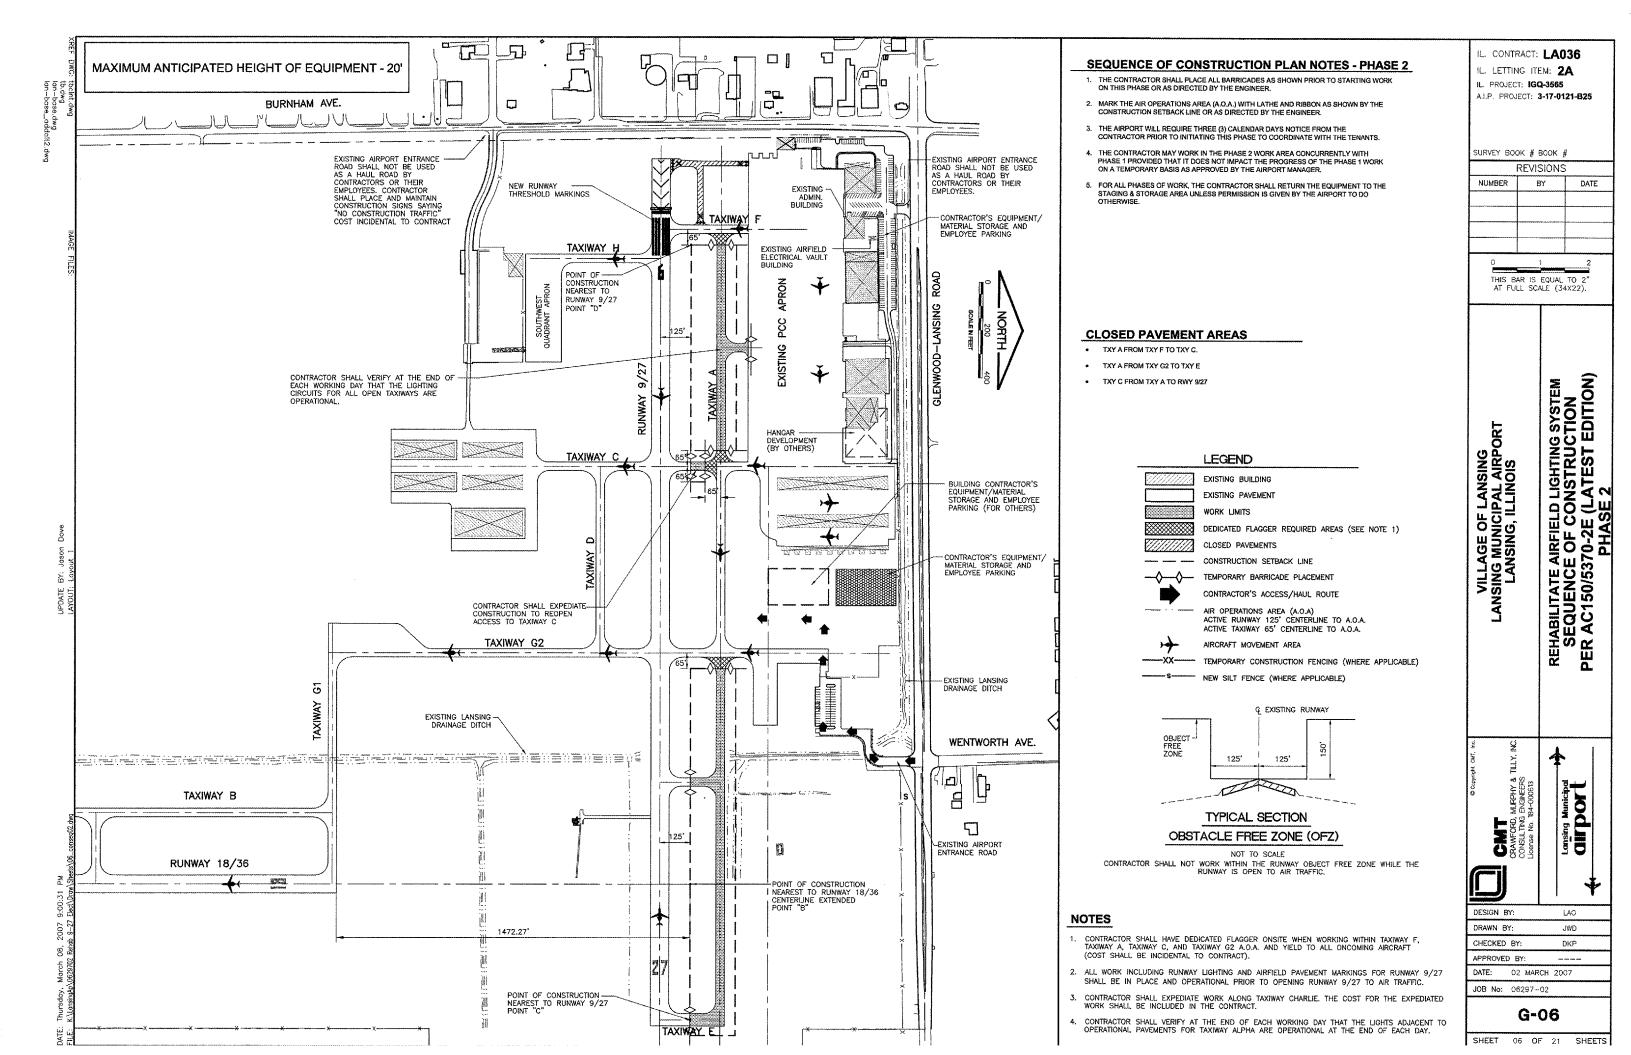

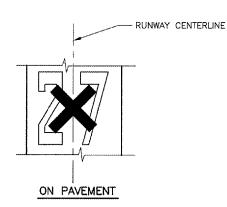


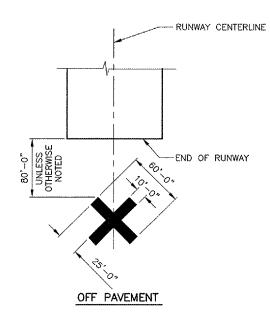


CLOSED RUNWAY MARKER DETAIL N.T.S.

NOTES

- 1. MARKERS SHALL BE SOLID YELLOW.
- 2. MARKERS SHALL BE MATERIAL APPROVED BY THE ENGINEER.
- CONTRACTOR SHALL MAINTAIN AND RELOCATE MARKERS AS SHOWN ON THE PLANS OR AS NEEDED TO FACILITATE
- 4. MARKERS ON PAVEMENT SHALL BE PLACED OVER EXISTING RUNWAY NUMERALS AS SHOWN. HOWEVER, WHEN WORK IS NECESSARY FOR THAT AREA OR PAVEMENT IS OPEN TO TAXIING AIRCRAFT, THE MARKERS SHALL BE RELOCATED OFF THE PAVEMENT AS SHOWN ON THE DETAIL.
- 5. COST OF FURNISHING, INSTALLING, MAINTAINING, RELOCATING AND REMOVING MARKERS SHALL BE CONSIDERED INCIDENTAL
- DURING VARIOUS PHASES OF WORK, IT WILL BE NECESSARY TO CLOSE RUNWAYS TO AIR TRAFFIC ON A TEMPORARY BASIS AS COORDINATED WITH THE AIRPORT AND TOWER, WHERE APPLICABLE, PERSONNEL. THE CONTRACTOR SHALL MARK THE RUNWAYS TO BE CLOSED BY PLACING A YELLOW CROSS AT THE LOCATION AND DIMENSIONS DETAILED ON THIS SHEET. THE CROSSES ARE SHOWN ON THE RESPECTIVE RUNWAYS ACCORDING TO THE VARIOUS PHASES OF WORK AS DELINEATED IN THE CONSTRUCTION ACTIVITY PLANS.

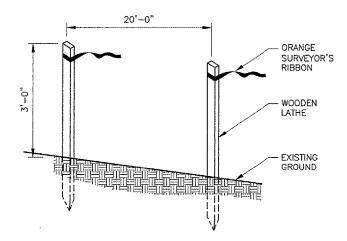

CONSTRUCTION SETBACK LINE DETAIL

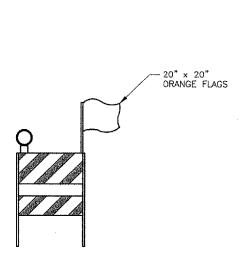


FLASHER BARRICADE DETAIL

N.T.S.

NOTES

- 1. FLASHERS TO BE BATTERY OPERATED. LENS TO BE RED AND BE ABLE TO ROTATE 90 DEGREES.
- 2. SANDBAGS TO BE PLACED ON EACH SUPPORT BRACE AS REQUIRED TO PREVENT DISPLACEMENT BY WIND, JET OR PROP BLAST.
- 3. NO SEPARATE PAYMENT WILL BE MADE FOR THIS ITEM. COSTS SHALL BE CONSIDERED INCIDENTAL TO THE
- 4. PLACE AT FIFTEEN-FOOT (15') INTERVALS.
- 5. ONE 20"x20" ORANGE FLAG TO BE INSTALLED ON EACH BARRICADE

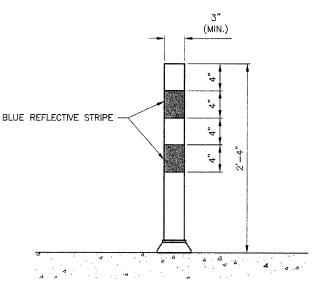


TEMPORARY TAXIWAY EDGE DELINEATOR

NOTES

- 2. SIMILAR TO IDOT STANDARD 702001-03, FLEXIBLE DELINEATOR.
- 3. DELINEATOR SHALL BE WEIGHTED DOWN (NOT ATTACHED) TO PAVEMENT TO PREVENT MOVEMENT BY WIND, PROP WASH OR JET BLAST. SAND BAGS MAY BE APPROVED FOR THIS.
- 4. REFLECTIVE STRIPES SHALL BE BLUE.

1. SPACED AT 25'-0" INTERVALS.

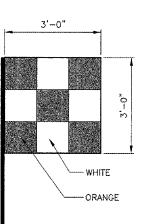


CONTRACTOR ACCESS ROUTE NOTES


- THE PROPOSED CONTRACTOR'S ACCESS ROUTE (EXISTING NORTH QUADRANT ACCESS ROAD FROM GLENWOOD-LANSING ROAD AND WENTWORTH AVENUE INTERSECTION) PAVEMENT
- 1.5" BITUMINOUS SURFACE COURSE (PLACED 2006) -EXCELLENT CONDITION
- 2.5" BITUMINOUS SURFACE COURSE (PLACED 2006) 8" CRUSHED AGGREGATE BASE COURSE (PLACED 2006)
- 2. THE CONTRACTOR MAY USE THE EXISTING NORTH QUADRANT ACCESS ROAD FOR ACCESS IF HE FEELS THE PAVEMENT STRUCTURE IS SUFFICIENT TO SUPPORT HIS OPERATIONS

WITHOUT DAMAGE OR DISTRESS

- IF THE CONTRACTOR ELECTS NOT TO USE THE EXISTING NORTH QUADRANT ACCESS ROAD PAVEMENT, HE SHALL CONSTRUCT AN ACCESS ROUTE SUFFICIENT TO SUPPORT HIS OPERATIONS FROM GLENWOOD-LANSING ROAD AT THE CONTRACTOR'S OWN
- ALL PAVEMENTS OR TURF AREAS UTILIZED BY THE CONTRACTOR FOR AN ACCESS ROUTE, STAGING, OR STORAGE SHALL BE REPAIRED AND RESTORED TO THEIR ORIGINAL CONDITION TO THE SATISFACTION OF THE AIRPORT, NO ADDITIONAL COMPENSATION TO PROTECT, REPAIR, OR RESTORE THSE AREAS SHALL BE MADE.

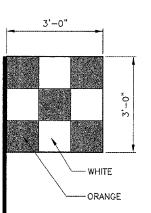

VEHICLE SIGNAL FLAG

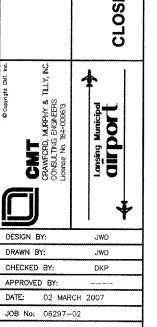

G-07

SHEETS

SHEET 07 OF 21

IL. CONTRACT: LA036 IL. LETTING ITEM: 2A IL. PROJECT: IGQ-3565 A.I.P. PROJECT: 3-17-0121-B25

SURVEY BOOK # BOOK #

NUMBER

VILLAGE OF LANSING LANSING MUNICIPAL AIRP LANSING, ILLINOIS


REVISIONS


BY


THIS BAR IS EQUAL TO 2 AT FULL SCALE (34X22).


DATE


REHABILITATE AIRFIELD LIGHTING SYSTEM SEQUENCE OF CONSTRUCTION D RUNWAY MARKER, FLASHER BARRICADI MISCELLANEOUS DETAILS

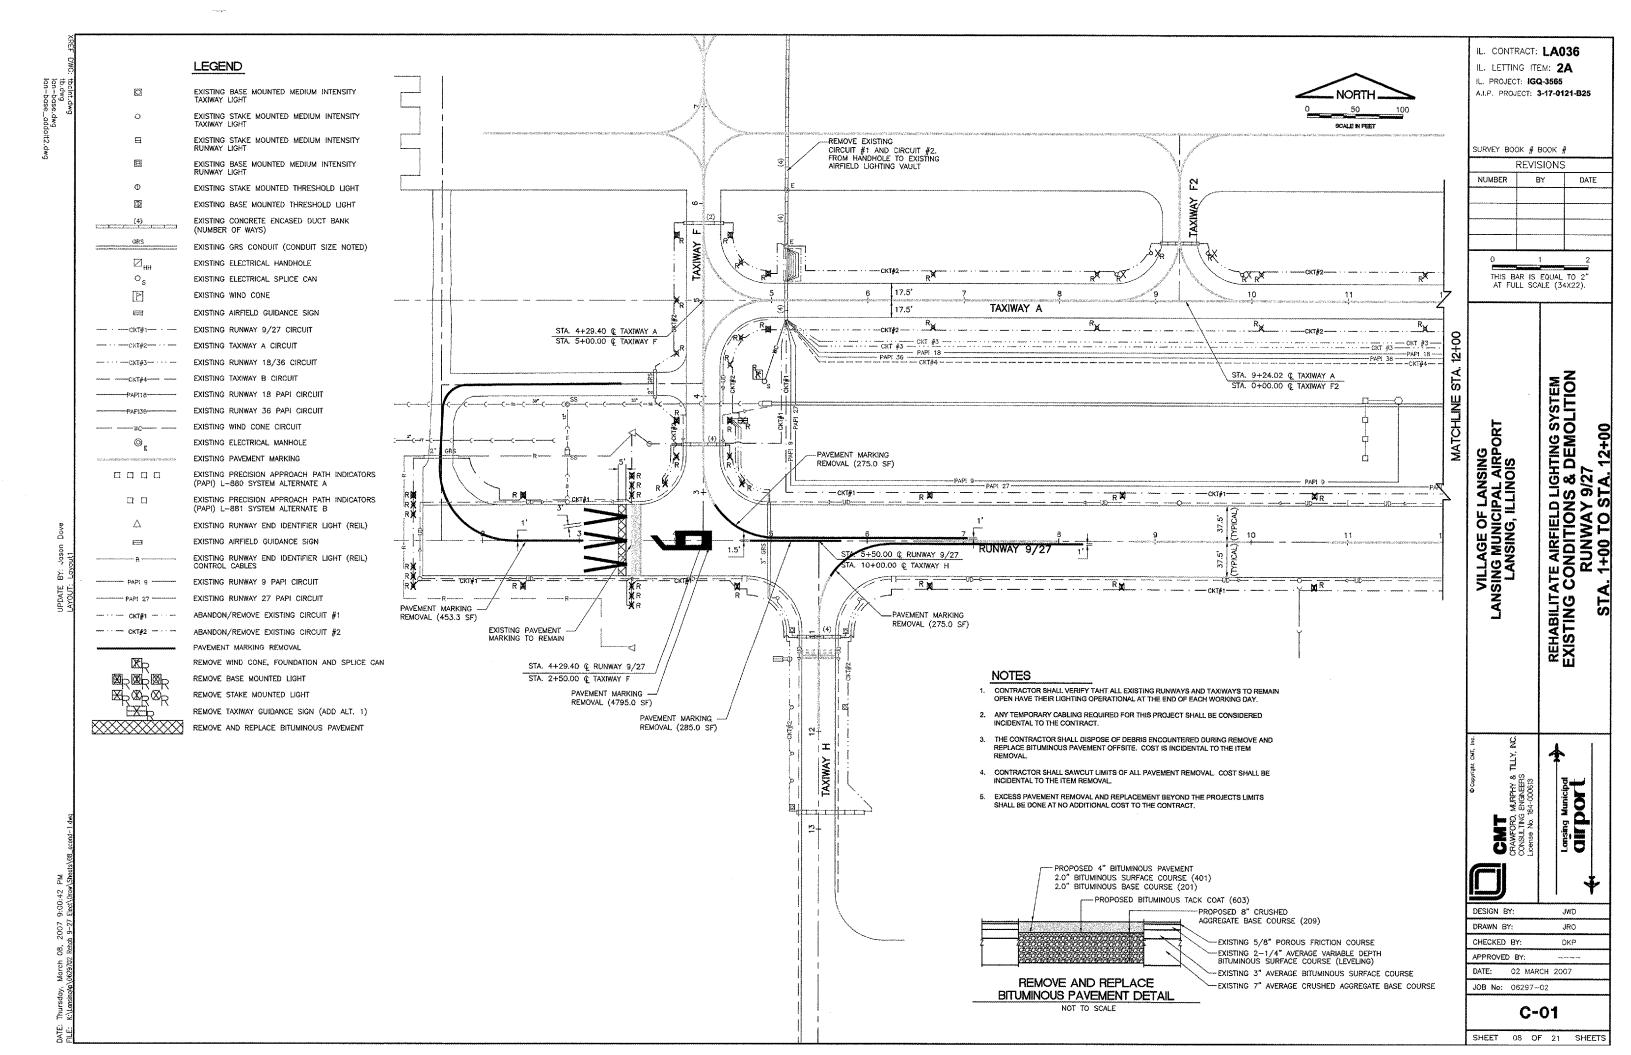

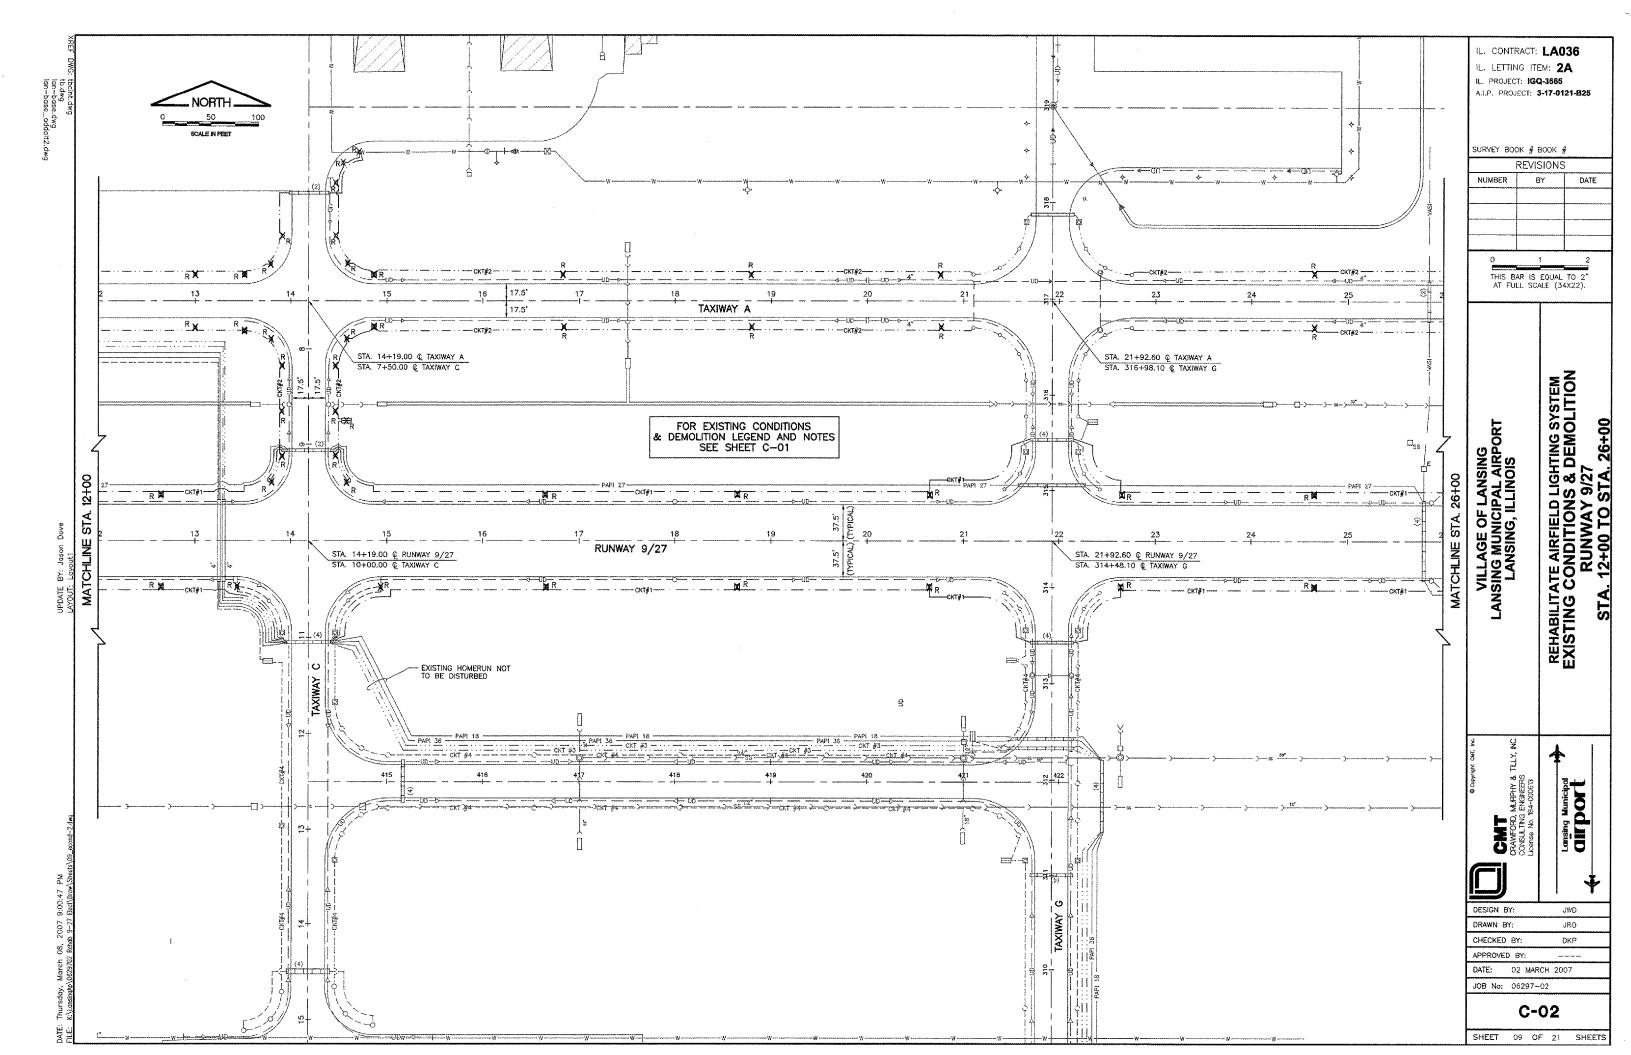

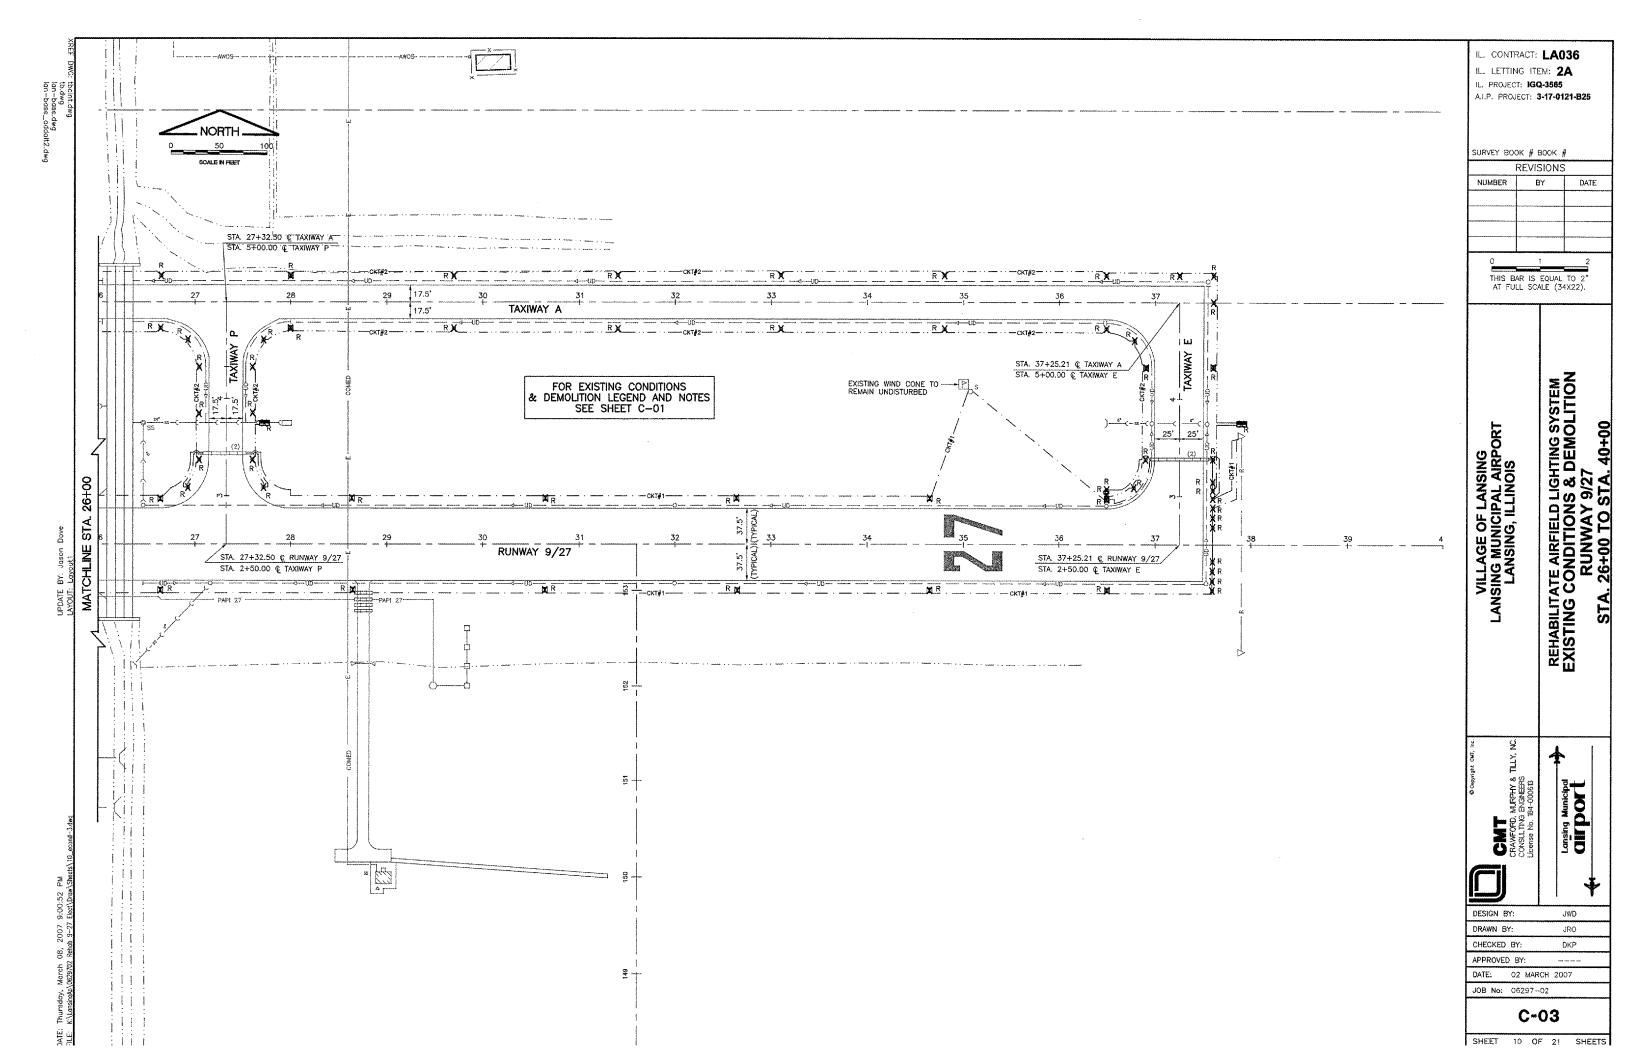

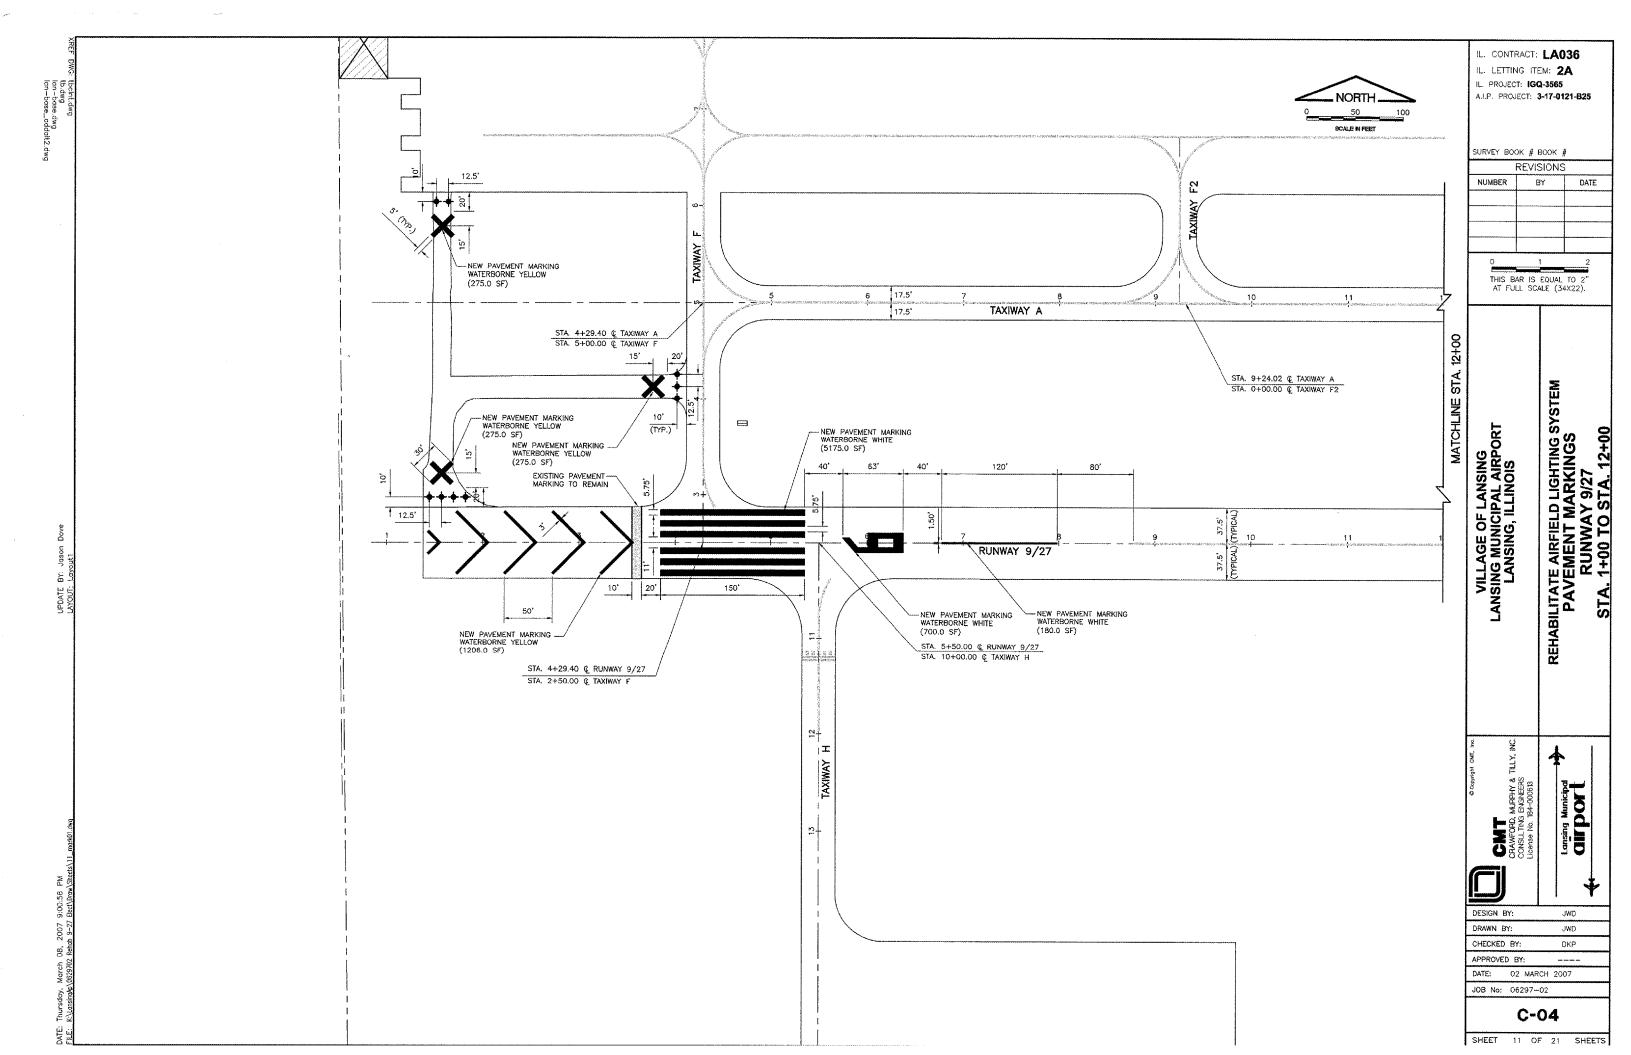

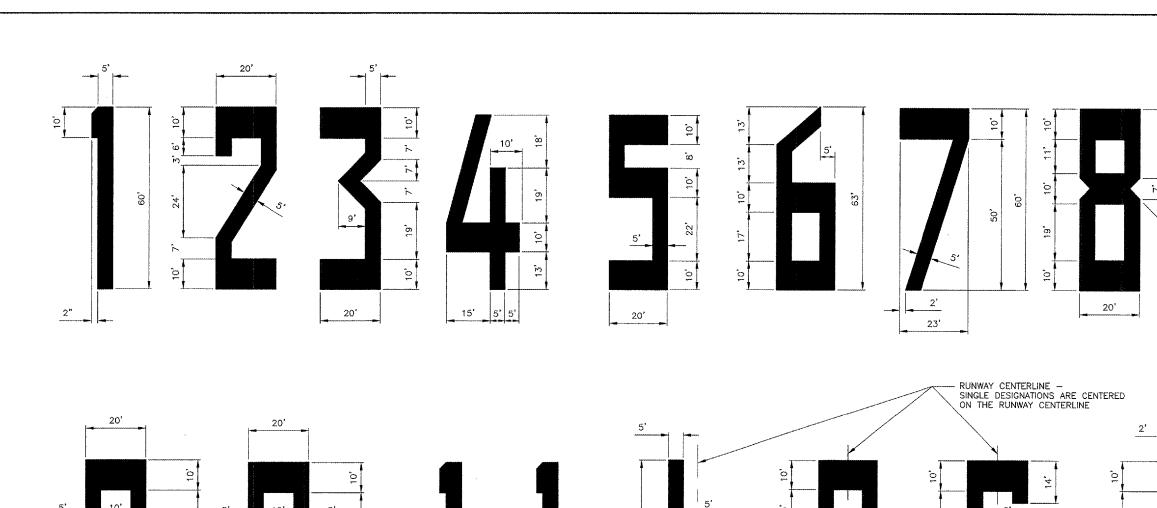

RUNWAY NUMERALS DETAIL

Ö

NOTE:

27'

37'

1. ALL NUMERALS EXCEPT THE NUMBER ELEVEN (11) AS SHOWN ARE HORIZONTALLY SPACED FIFTENN (15) FEET APART.

20"

- 2. SINGLE DIGITS SHALL NOT BE PRECEDED BY A ZERO
- 3. DIMENSIONS ARE EXPRESSED IN FEET.
- 4. THE NUMERAL ONE (1), WHEN USED ALONE, CONTAINS A HORIZONTAL BAR TO DIFFERENTIATE IT FROM THE RUNWAY CENTERLINE MARKING.

, 0

20"

5'

20'

- SINGLE DESIGNATIONS ARE CENTERED ON THE RUNWAY PAVEMENT CENTERLINE. FOR DOUBLE DESIGNATIONS, THE CENTER OF THE OUTER EDGES OF THE TWO NUMERALS IS CENTERED ON THE RUNWAY PAVEMENT CENTERLINE.
- WHERE THE RUNWAY DESIGNATION CONSISTS OF A NUMBER AND A LETTER, THE NUMBER AND LETTER ARE LOCATED ON THE RUNWAY CENTERLINE IN A STACKED ARRANGEMENT.

45' 5' 10'


ARROWHEAD AND THRESHOLD BAR DETAILS

NOTE:

1. ALL PROPOSED YELLOW AND WHITE MARKING SHALL HAVE REFLECTIVE BEADS.

THRESHOLD BAR ---


ALL PROPOSED WHITE MARKINGS SHALL HAVE 6" BLACK BORDER.

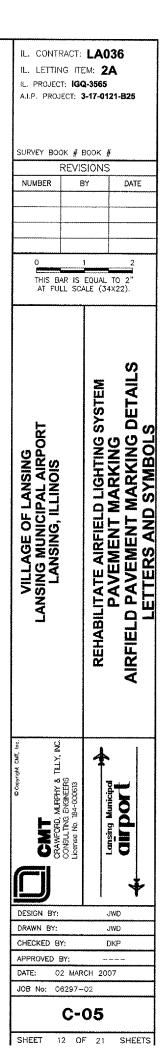



7.5


20'


(SEE NOTE 4)

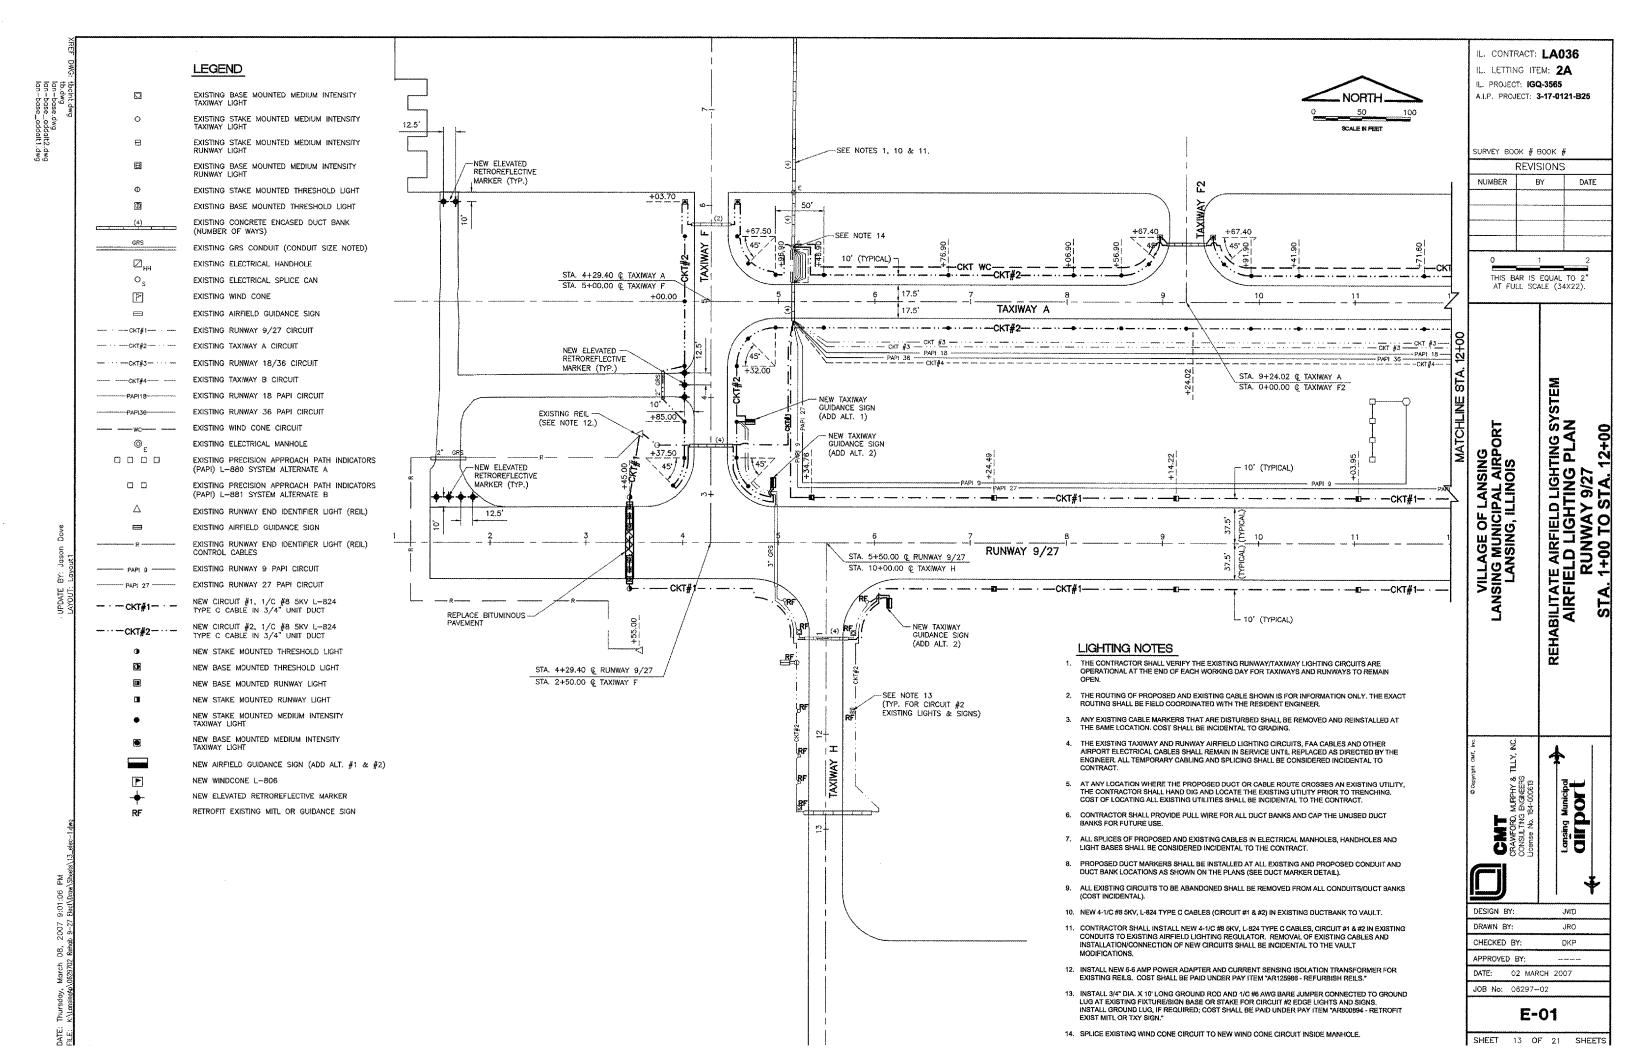

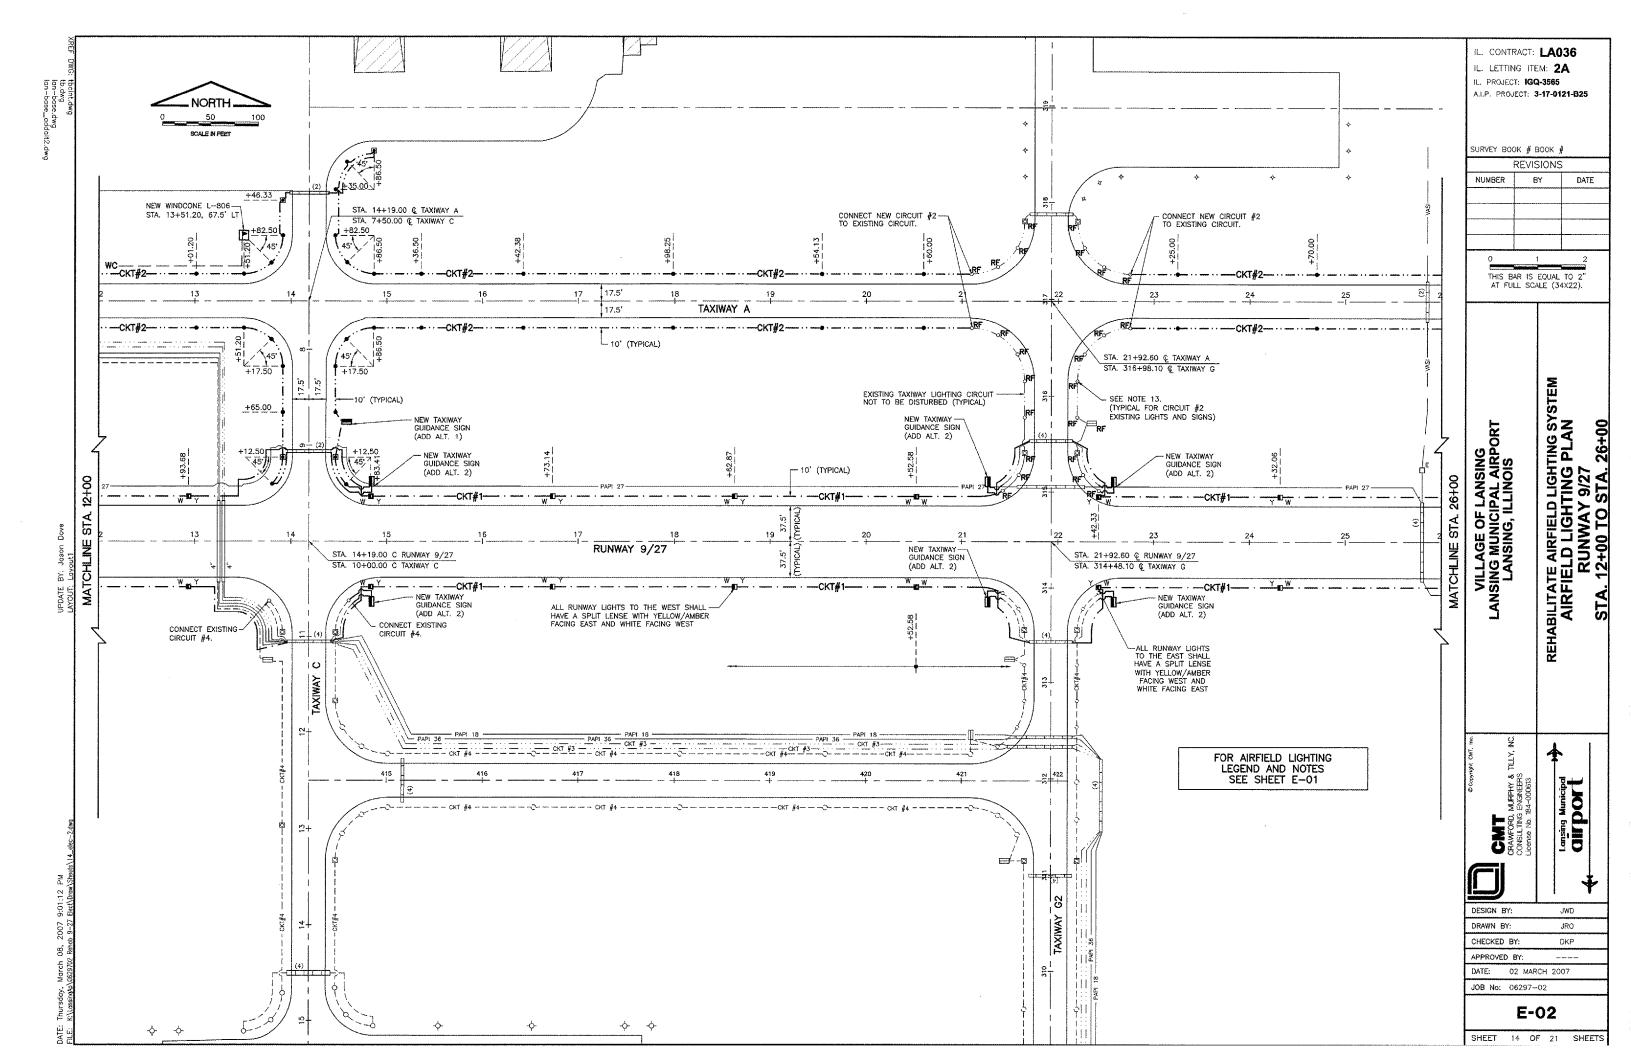

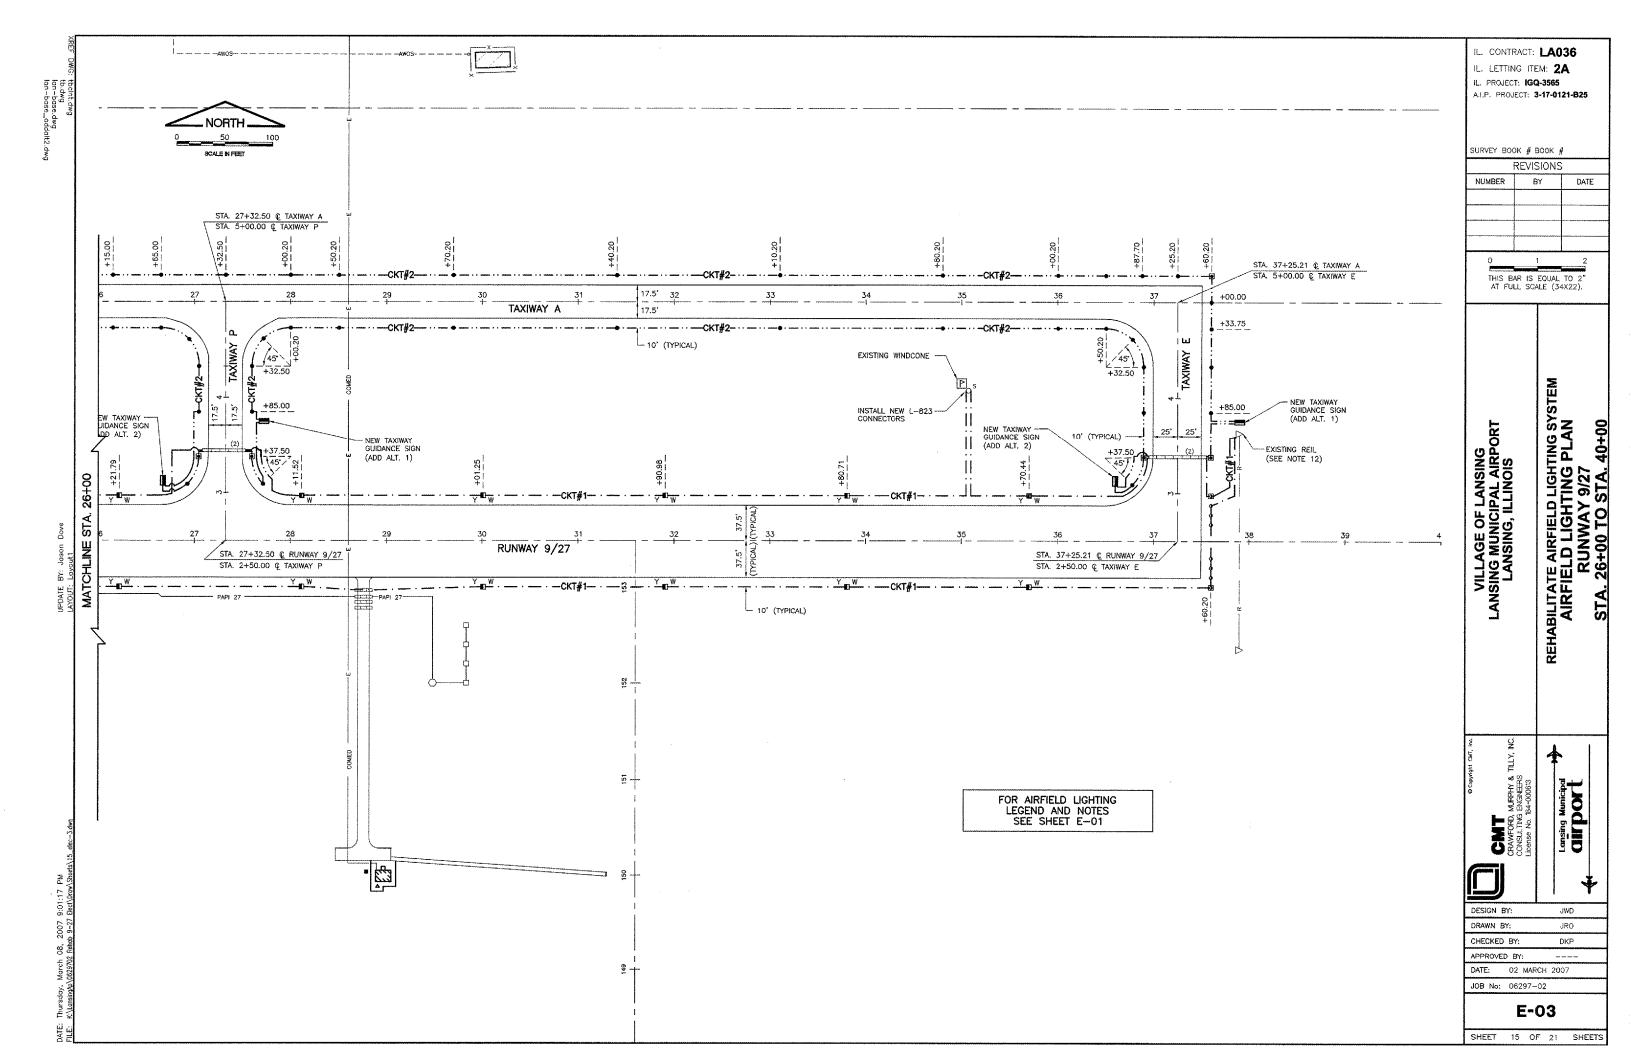

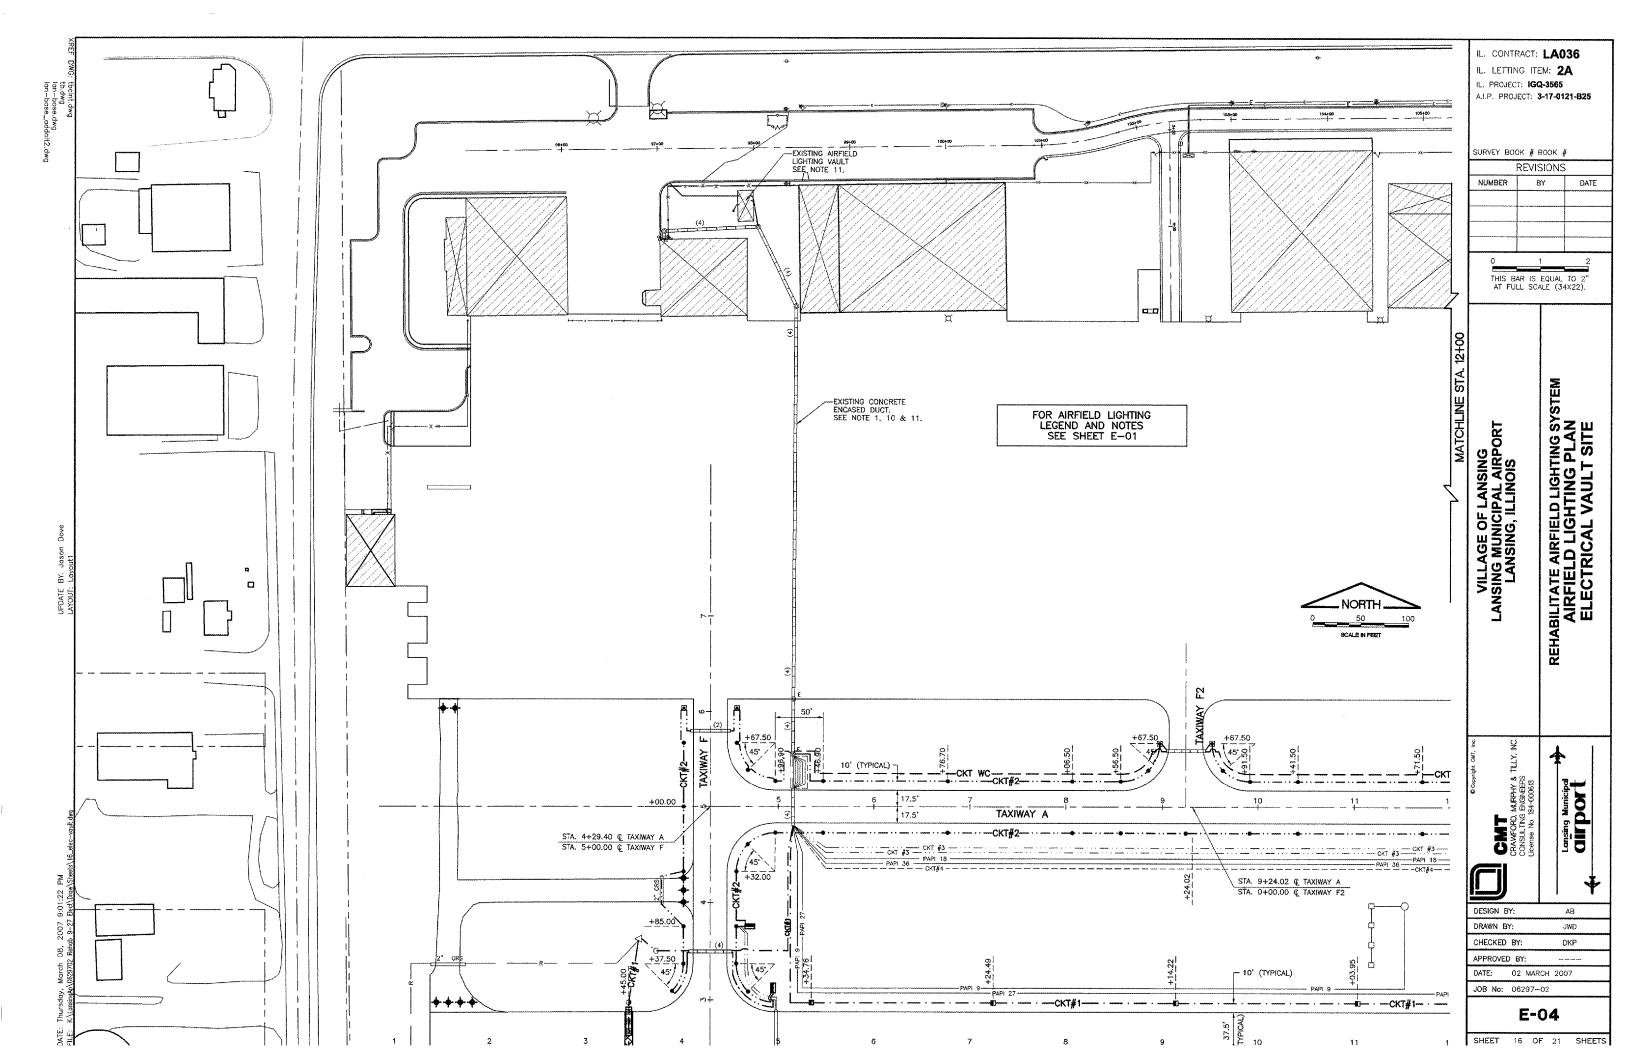

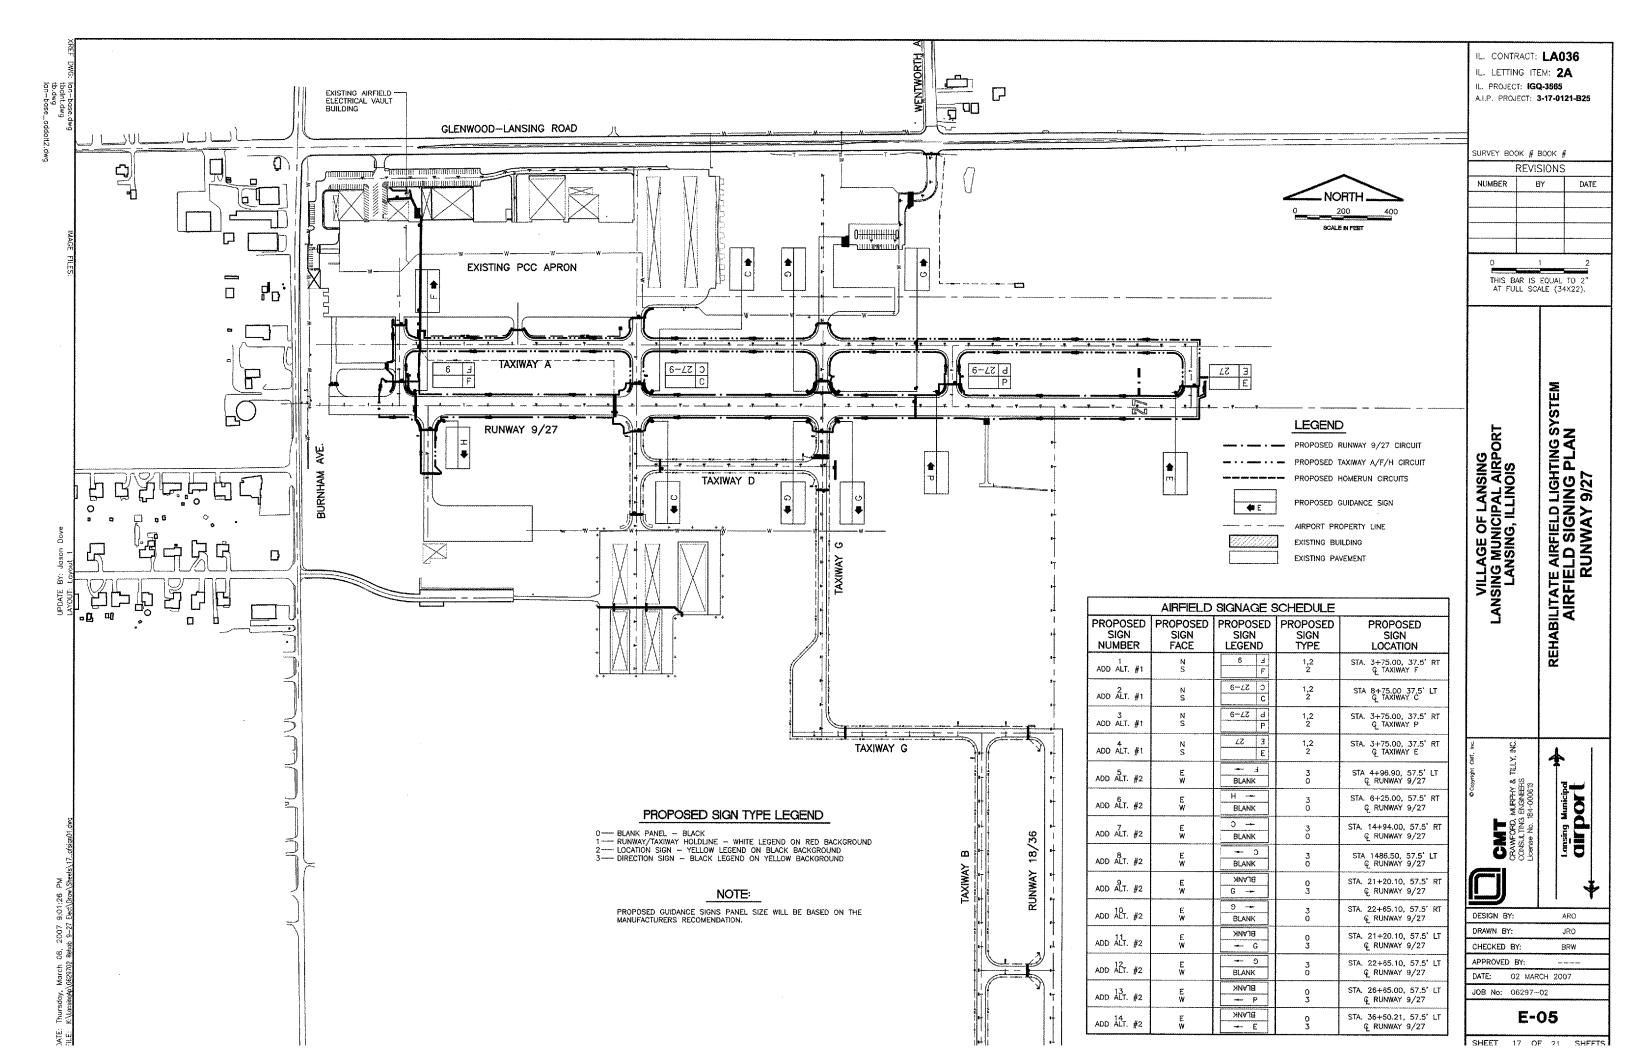

GRS CONDUIT

FINISH GRADE

PROPOSED CA-6 AGGREGATE-BASE (208) COMPACTED TO 95% STANDARD PROCTOR (COST INCIDENTAL TO PROPOSED CONDUIT)

SAND 1/4" SIEVE MAX.


"R" MIN AND 12"

--- SEE PLAN VIEW

FOR PAVEMENT THICKNESS

PAVEMENT


CONCRETE ENCASED DUCT BACKFILL

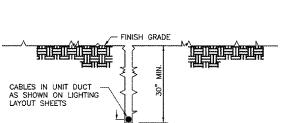

CABLE IN UNIT DUCT - PLOWED

NOT TO SCALE

NOTE: CONTRACTOR SHALL HAVE THE OPTION TO TRENCH OR PLOW UNIT DUCT. NO ADDITIONAL PAYMENT SHALL BE MADE FOR TRENCHING.

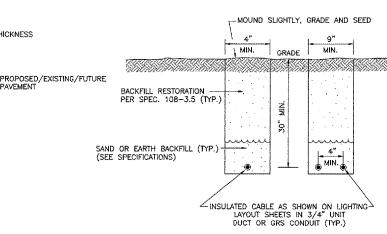

TURF AREA CABLE TRENCH DETAIL

NOT TO SCALE

NOTES

CONCRETE

ARROW TO INDICATE -THE DIRECTION OF THE CABLE RUN

NOTES

- 1. TRENCHES WITH MORE THAN 2 CABLES SHALL BE INCREASED 4" IN WIDTH FOR EACH ADDITIONAL CABLE. IF SPECIFIED ON PLANS, TWO PARALLEL TRENCHES MAY BE CONSTRUCTED
- DEPTH OF TRENCHES SHALL BE AS SHOWN UNLESS OTHERWISE SPECIFIED ON THE PLANS.
- SAND BACKFILL SHALL BE USED IF THE EXISTING SOIL DOES NOT MEET THE BACKFILL REQUIREMENTS.
- 4. ALL DISTURBED SURFACES SHALL BE RESTORED TO THEIR ORIGINAL CONDITION. COST IS INCIDENTAL.

CABLE

TURF CABLE MARKER DETAIL

1.) CABLE MARKERS SHALL BE INSTALLED AT ALL

3.) ALL EXPOSED EDGES SHALL BE EDGED WITH

4.) THE COST OF FURNISHING AND INSTALLING NEW MARKERS SHALL BE INCIDENTAL TO THE ASSOCIATED CABLE ITEMS.

CONTACTOR SHALL LOCATE EXISTING CABLE

MARKERS IN THE FIELD BEFORE SHOULDER

ADJUSTMENT BEGINS IN ORDER TO REPLACE CABLE MARKERS AT CORRECT LOCATIONS (COST INCIDENTAL TO CONTRACT).


2.) ITEM 610 CONCRETE SHALL BE USED.

5.) 0.049 CU. YD. CONCRETE PER MARKER.

BENDS AND EVERY 200' ALONG THE CABLE RUN.


INSTALL FLUSH

WITH GROUND

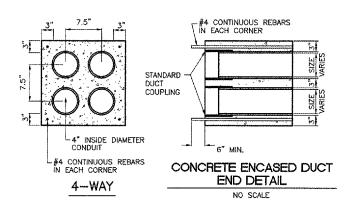

CONCRETE ENCASED DUCT BANKS

- 1. DIMENSIONS ARE MINIMUM
- 2. CONCRETE SHALL CONFORM TO ITEM 610.
- 3. ALL CONDUIT SHALL BE SCHEDULE 40 PVC.
- 4. TOP OF CONCRETE ENCASEMENT IN TURF AREAS SHALL NOT BE LESS THAN 24" BELOW FINISHED
- 5. 4" SPLIT DUCT SHALL BE CONCRETE ENCASED WITH 3" MINIMUM CONCRETE SURROUNDING 4" CONDUIT. COST INCIDENTAL TO SPLIT DUCT.
- 6. PROVIDE PULL STRING AND CAPS FOR UNUSED

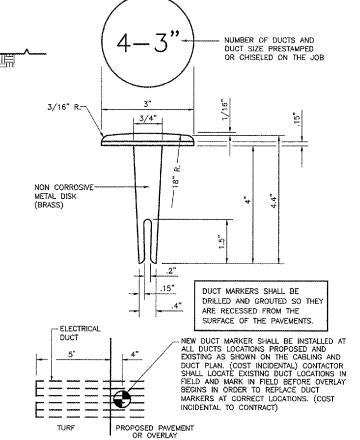


DUCT MARKER DETAIL

PROPOSED I/C, #8 L-824, TYPE C-5KV AIRFIELD LIGHTING CABLE IN 3/4" UNIT DUCT OR PVC CONDUIT (TYP.) FROM LAST NEW RUNWAY/ TAXIWAY LIGHT CONTRACTOR SHALL INSTALL HEAT SHRINK TUBING AT ALL TERMINATIONS OF UNIT DUCT LIGHT CAN CONNECT PROPOSED CABLE IF BASE MOUNTED TO EXISTING CABLE AT L-823 PRIMARY CABLE CONNECTOR WITH TAPING AND HEAT SHRINK EXISTING CABLE TO NEXT RUNWAY / TAXIWAY LIGHT EXISTING SECONDARY LEAD TO LIGHT

RUNWAY/TAXIWAY LIGHTING CIRCUIT CONNECTION DETAIL

NOT TO SCALE

EXISTING ISOLATION TRANSFORMER

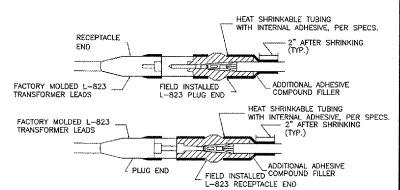

TYPE C AND D - CABLE SPLICE

FOR SPLICES AT RUNWAY/TAXIWAY LIGHTS AND SIGNS NOT TO SCALE

CABLE SPLICE NOTES

- 1. INSIDE DIAMETER OF CONNECTOR SHALL PROPERLY MATCH THE OUTSIDE DIAMETER OF CABLE.
- 2. WRAP WITH AT LEAST ONE LAYER OF RUBBER OR SYNTHETIC RUBBER TAPE AND ONE LAYER OF PLASTIC TAPE, ONE-HALF LAPPED, EXTENDING AT LEAST 1-1/2 INCHES ON EACH SIDE OF JOINT.
- THE COST OF FURNISHING AND INSTALLING ALL SPUCE MATERIALS SHALL BE INCIDENTAL TO THE ASSOCIATED CABLE ITEMS.
- 4. THE CONTRACTOR SHALL HAVE A MINIMUM OF TWO (2) TYPE A SPLICE KITS ON THE JOB SITE AT ALL TIMES FOR EMERGENCY REPAIRS.

GERERAL NOTES:

- THE CONCRETE BASE FOR BASE MTD. LIGHTS SHALL BE TROWEL FINISHED WITH A 45° BEVELED EDGE. SLOPE TO DRAIN (610).
- 2. TRANSFORMER HOLDER SHALL BE ANY COMMERCIALLY AVAILABLE BRICK.
- 3. BREAKING GROOVE COUPLINGS SHALL NOT BE OVER 1" ABOVE GROUND LINE
- ISOLATION TRANSFORMERS COME WITH A FACTORY INSTALLED PLUG (TYPE 1, SOCIATION TRANSFORMERS COME WITH A FACTORY INSTALLED PLOG (THE CLASS A, STYLE 9).
 A TYPE 1, CLASS B, STYLE 3 PLUG AND TYPE 1, CLASS B, STYLE 10
 RECEPTACLE SHALL BE INSTALLED ON THE 1/C, No. 8, 5000 V., L-824
 TYPE C CABLES FOR CONNECTION TO EACH TRANSFORMER.
- TO FURTHER REDUCE THE POSSIBILITY OF WATER/MOISTURE ENTRANCE INTO THE CONNECTOR BETWEEN THE CABLE AND THE FIELD ATTACHED CONNECTOR, IT IS REQUIRED THAT A HEAT SHRINKABLE TUBING WITH INTERNAL ADHESIVE BE APPLIED OVER THE ENTIRE CABLE CONNECTOR.
- ALL SIGNS, LIGHTS, CABLES AND TRANSFORMERS TO BE REMOVED SHALL REMAIN THE PROPERTY OF THE AIRPORT. AT THE DISCRETION OF THE AIRPORT MANAGER, THE CONTRACTOR MAY BE REQUIRED TO DISPOSE OF THESE MATERIALS OFFSITE AT NO ADDITIONAL COST.
- TAXIWAY LIGHTS SHALL HAVE A BLUE LENS, RUNWAY LIGHTS SHALL HAVE A CLEAR OR 180' AMBER/CLEAR LENS AS DESIGNATED ON PLANS.
- 8. DUCT MARKERS SHALL BE INSTALLED AT EVERY NEW DUCT AND AT EVERY EXISTING DUCT USED FOR THIS PROJECT.
- 9. CONTRACTOR SHALL HAVE THE OPTION TO TRENCH OR PLOW UNIT DUCT. NO ADDITIONAL PAYMENT SHALL BE MADE FOR TRENCHING.

IL. LETTING ITEM: 2A IL. PROJECT: IGQ-3565 A.I.P. PROJECT: 3-17-0121-B25 SURVEY BOOK # BOOK # REVISIONS NUMBER BY DATE

IL. CONTRACT: LA036

THIS BAR IS EQUAL TO 2 AT FULL SCALE (34X22)

REHABILITATE AIRFIELD LIGHTING SY ELECTRICAL DETAILS AIRFIELD LIGHTING DETAIL GENERAL DETAILS OR. VILLAGE OF LANSING LANSING MUNICIPAL AIRP LANSING, ILLINOIS


DESIGN BY ARM

DRAWN BY JRO CHECKED BY APPROVED BY: DATE: 02 MARCH 2007 JOB No: 06297-02


E-06

SHEET 18 OF 21 SHEETS

86.5

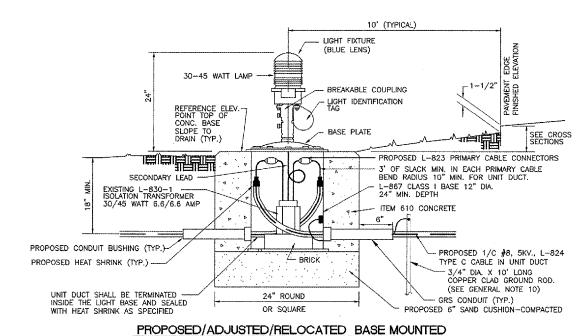


MEDIUM INTENSITY TAXIWAY LIGHT NOT TO SCALE

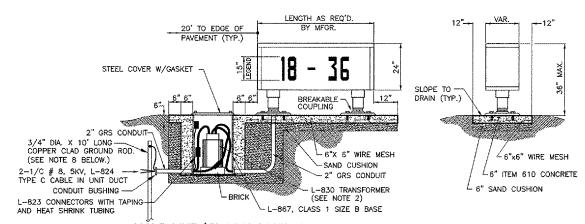

HOLD LINE / TAXIWAY GUIDANCE SIGN L-858, SIZE 2, STYLE 2, CLASS 2 NOT TO SCALE


SIGNAGE NOTES

- 1. ALL SIGNS ARE LUMACURVE 2-SIDED SIGNS BY STANDARD SIGNS OR APPROVED EQUAL
- 2. TRANSFORMER WATTAGE AS RECOMMENDED BY MANUFACTURER.
- 3. LIGHTED SIGNS SHALL BE BASE MOUNTED ONLY.
- 4. UNIT DUCT SHALL BE TERMINATED IN THE CAN AND SEALED TO THE CABLE WITH HEAT SHRINK AS SPECIFIED.
- 5. THE NUMBER OF MODULES PER SIGN SHALL BE AS RECOMMENDED BY THE MANUFACTURER
- CONTRACTOR SHALL SUBMIT DETAILED SHOP DRAWING INCLUDING SIGN, COLOR, SIZE AND PROPOSED LEGEND, IN ENOUGH DETAIL AND DETERMINE PROPOSED SPACING AND OTHER INFORMATION REQUIRED BY SPECIAL PROVISIONS. CONTRACTOR TO VERIFY PROPOSED SIGN LOCATIONS AND ORIENTATIONS WITH RESIDENT ENGINEER PRIOR TO INSTALLATION.
- 7. WHEN EXISTING SIGNS ARE PROPOSED TO BE RETROFITTED WITH NEW SIGN PANELS. THE SIGN PANELS SHALL CONFORM TO THE APPLICABLE REQUIREMENTS OF ADVISORY CIRCULAR 150/5340-18 (LATEST EDITION). THE CONTRACTOR SHALL VERIFY THAT THE PROPOSED SIGN PANELS ARE COMPATIBLE WITH THE EXISTING SIGN ASSEMBLIES WHICH ARE LUMACURVE BY STANDARD SIGNS.
- INSTALL 1/C #6 AWG BARE COPPER GROUND JUMPER CONNECTED TO GROUND LUG INSIDE BASE CAN AND EXOTHERMICALLY WELDED TO GROUND ROD. INSTALL GROUND LUG FOR EXISTING CANS, IF REQUIRED.

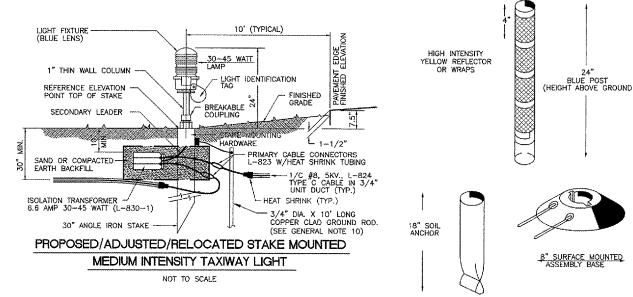

ELEVATED RETROREFLECTIVE MARKER DETAIL

NOTE: RETROREFLECTIVE MARKER SHALL BE SAFE-HIT OR APPROVED EQUAL.

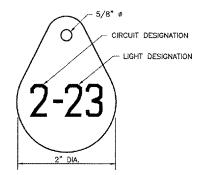


LIGHT IDENTIFICATION DETAIL

NOTES:


- INSTALL A NONCORROSIVE DISC OF 2"
 MINIMUM DIAMETER WITH THE NUMBER
 PERMANENTLY STAMPED, CUT OUT, OR
 ENGRAVED UNDER THE HEAD OF THE BASE
 PLATE BOLT OR ATTACHED TO LIGHT
 FLANGE WITH A SET SCREW.
- 2. NUMERALS SHOWN ARE FOR ILLUSTRATIVE PURPOSES ONLY, ALL EXISTING AND PROPOSED TAXIWAY AND RUNWAY LIGHTS SHALL BE TAGGED AS DIRECTED BY THE RESIDENT ENGINEER. ALL LIGHTS ON EXISTING CIRCUITS THAT HAVE LIGHTING MPROVEMENTS (PROPOSED OR RELOCATED LIGHTS) SHALL BE RETAGGED.
- 3. COST OF TAGGING LIGHTS SHALL NOT BE PAID FOR SEPERATELY BUT SHALL BE CONSIDERED INCIDENTAL TO THE CONTRACT

GERERAL NOTES:

- 1. THE CONCRETE BASE FOR BASE MOUNTED LIGHTS SHALL BE TROWEL FINISHED WITH A 45' BEVELED EDGE. SLOPE TO DRAIN (610).
- 2. TRANSFORMER HOLDER SHALL BE ANY COMMERCIALLY AVAILABLE BRICK.
- 3. BREAKING GROOVE COUPLINGS SHALL NOT BE OVER 1" ABOVE GROUND LINE.
- 4. ISOLATION TRANSFORMERS COME WITH A FACTORY INSTALLED PLUG (TYPE 1, CLASS A, STYLE 2) AND RECEPTACLE (TYPE 1, CLASS A, STYLE 9). A TYPE 1, CLASS B, STYLE 3 PLUG AND TYPE 1, CLASS B, STYLE 10 RECEPTACLE SHALL BE INSTALLED ON THE 1/C, No. 8, 5000 V., L-824 TYPE C CABLES FOR CONNECTION TO EACH TRANSFORMER.
- 5. TO FURTHER REDUCE THE POSSIBILITY OF WATER/MOISTURE ENTRANCE INTO THE CONNECTOR BETWEEN THE CABLE AND THE FIELD ATTACHED CONNECTOR, IT IS REQUIRED THAT A HEAT SHRINKABLE TUBING WITH INTERNAL ADHESIVE BE APPLIED
- 6. ALL SIGNS, LIGHTS, CABLES AND TRANSFORMERS TO BE REMOVED SHALL REMAIN THE PROPERTY OF THE AIRPORT. AT THE DISCRETION OF THE AIRPORT MANAGER, THE CONTRACTOR MAY BE REQUIRED TO DISPOSE OF THESE MATERIALS OFFSITE AT NO
- 7. TAXIWAY LIGHTS SHALL HAVE A BLUE LENS, RUNWAY LIGHTS SHALL HAVE A CLEAR OR 180' AMBER/CLEAR LENS AS DESIGNATED ON PLANS.
- DUCT MARKERS SHALL BE INSTALLED AT EVERY NEW DUCT AND AT EVERY EXISTING DUCT USED FOR THIS PROJECT.
- CONTRACTOR SHALL HAVE THE OPTION TO TRENCH OR PLOW UNIT DUCT. NO ADDITIONAL PAYMENT SHALL BE MADE FOR TRENCHING.
- 10. INSTALL 1/C #6 AWG BARE COPPER GROUND JUMPER CONNECTED TO GROUND LUG INSIDE BASE CAN OR STAKE AND EXOTHERMICALLY WELDED TO GROUND ROD. INSTALL GROUND LUG FOR EXISTING CANS AND STAKES, IF REQUIRED. INSTALLING GROUND LUGS FOR EXISTING CANS AND STAKES SHALL BE AT NO ADDITIONAL COST.

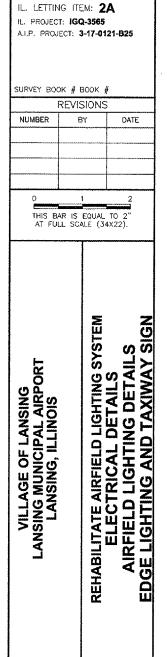

IL. CONTRACT: LA036

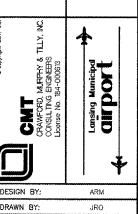

CHECKED BY: DKP APPROVED BY: DATE: 02 MARCH 2007 JOB No: 06297-02

E-07

SHEET SHEETS 19 OF 21

HALF RUNWAY HALF RUNWAY WIDTH RUNWAY PAVEMENT END OF RUNWAY PROPOSED PAVEMENT REMOVAL AND REPLACEMENT PROPOSED THRESHOLD LIGHT IN PROPOSED ITEM 610 CONCRETE PROPOSED RUNWAY THRESHOLD LIGHT BAR (AR800187) PROPOSED TROWELED CONTRACTION JOINT EVERY 10' 1.5 NEW ITEM 610 CONCRETE EXISTING BLAST PAD 10' (TYPICAL) 10' (TYPICAL)

RUNWAY THRESHOLD LIGHTING PLAN

ITEM AR800187 THRESHOLD LIGHT BAR SHALL INCLUDE CONDUIT, ITEM 610 CONCRETE, REINFORCEMENT, SAWCUTTING, BEDDING, AND ALL INCIDENTALS FOR A COMPLETE AND OPERATIONAL SYSTEM, PER EACH END.


17.5' TO RUNWAY 9/27 CENTERLINE PROPOSED THRESHOLD LIGHT FIXTURE PER PLANS (SEE DETAIL) PROPOSED DEFORMED WIRE FABRIC (ASTM A-185) 0.05% 6" MINIMUM IN BOTH DIRECTIONS PROPOSED PVC TO GRSC CONNECTOR TO NEXT THRESHOLD CABLE IN UNIT DUCT 3/4" DIA. X 10' LONG COPPER CLAD GROUND ROD. (SEE GENERAL NOTE 7) PROPOSED 6" SAND PROPOSED L-868 CLASS SIZE B, BASE CAN (SEE BASE MOUNTED THRESHOLD LIGHT DETAIL COMPACTED SUBGRADE FOR INSTALLATION DETAILS INSIDE CAN)

SECTION A-A THRESHOLD LIGHTS, BASE MOUNTED

NOT TO SCALE


GERERAL NOTES:

- 1. THE CONCRETE BASE FOR BASE MTD. LIGHTS SHALL BE TROWEL FINISHED WITH A 45° BEVELED EDGE. SLOPE TO
- 2. TRANSFORMER HOLDER SHALL BE ANY COMMERCIALLY AVAILABLE BRICK.
- 3. BREAKING GROOVE COUPLINGS SHALL NOT BE OVER 1" ABOVE GROUND LINE
- 4. ISOLATION TRANSFORMERS COME WITH A FACTORY INSTALLED PLUG (TYPE 1, CLASS A, STYLE 2) AND RECEPTACLE (TYPE 1, CLASS A, STYLE 9). A TYPE 1, CLASS B, STYLE 3 PLUG AND TYPE 1, CLASS B, STYLE 10 RECEPTACLE SHALL BE INSTALLED ON THE 1/C, No. 8, 5000 V., L-824 TYPE C CABLES FOR CONNECTION TO EACH TRANSFORMER.
- TO FURTHER REDUCE THE POSSIBILITY OF WATER/MOISTURE ENTRANCE INTO THE CONNECTOR BETWEEN THE
 CABLE AND THE FIELD ATTACHED CONNECTOR, IT IS REQUIRED THAT A HEAT SHRINKABLE TUBING WITH INTERNAL
 ADHESIVE 8E APPLIED OVER THE ENTIRE CABLE CONNECTOR.
- 6. THRESHOLD LIGHTS SHALL HAVE A 180° GREEN/RED LENS.
- 7. INSTALL 1/C #6 AWG BARE COPPER GROUND JUMPER CONNECTED TO GROUND LUG INSIDE BASE CAN OR STAKE AND EXOTHERMICALLY WELDED TO GROUND ROD.

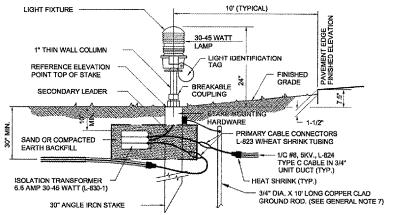


STAKE MOUNTED RUNWAY EDGE/THRESHOLD LIGHT DETAIL

NOT TO SCALE

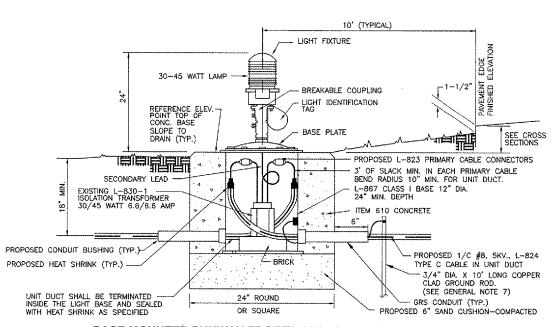

BASE MOUNTED RUNWAY EDGE/THRESHOLD LIGHT DETAIL

IL. CONTRACT: LA036 IL. LETTING ITEM: 2A IL. PROJECT: IGQ-3565 A.I.P. PROJECT: 3-17-0121-B25 SURVEY BOOK # BOOK # REVISIONS NUMBER BY DATE THIS BAR IS EQUAL TO 2 AT FULL SCALE (34X22) VILLAGE OF LANSING LANSING MUNICIPAL AIRPORT LANSING, ILLINOIS REHABILITATE AIRFIELD LIGHTING S ELECTRICAL DETAILS AIRFIELD LIGHTING DETAI THRESHOLD LIGHTS

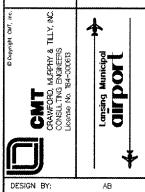


DRAWN BY: JWD CHECKED BY: AB APPROVED BY: DATE: 02 MARCH 2007

E-08

SHEET 20 OF 21


JOB No: 06297-02



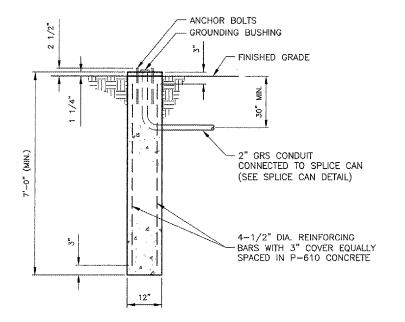


SECTION A-A GROUNDING BUSHING. CONNECT TO GROUNDING LUG IN STEEL BASE. NUMBER, SIZE AND LOCATION OF ANCHOR BOLTS PER CYLINDRICAL MANUFACTURER FOUNDATION 2" GRS CONDUIT CONNECTED TO SPLICE CAN (SEE SPLICE CAN DETAIL) PLAN

WIND CONE FOUNDATION NOT TO SCALE

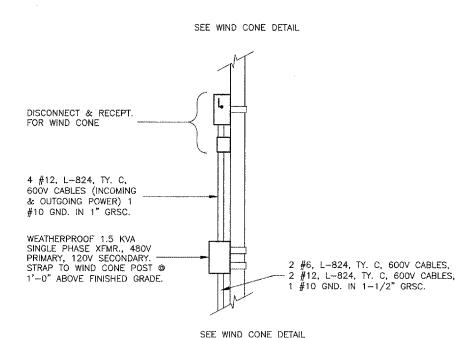

NEMA 3R DISCONNECT AND WEATHERPROOF GFCI RECEPTACLE DETAIL

PROPOSED 3/4" THICK AND OUTGOING POWER SOLID STEEL COVER WITH WIRING (SEE WIND CONE BOLT ON LID DETAIL) FINISHED -GRADE (MIN.) PROPOSED CONCRETE (ITEM 610) 8 PROPOSED L-867B CLASS 1, SIZE B CAN WITH THREE (3) COUPLINGS. INCOMMING POWER 2 #6, L-824, TY. C, 600V CABLES 2" GRS CONDUIT——/
CONNECTED TO WIND CONE 1 #10 GND. IN 1" UNIT DUCT. PROPOSED 2" G.R.S. FOUNDATION (SEE WIND CONE FOUNDATION DETAIL) 3/4" DIA. X 10' LONG PROPOSED SAND CUSHION COPPER CLAD GROUND ROD MIN. BURY 1'-0". WIND CONE SPLICE CAN DETAIL (SEE NOTE 5)

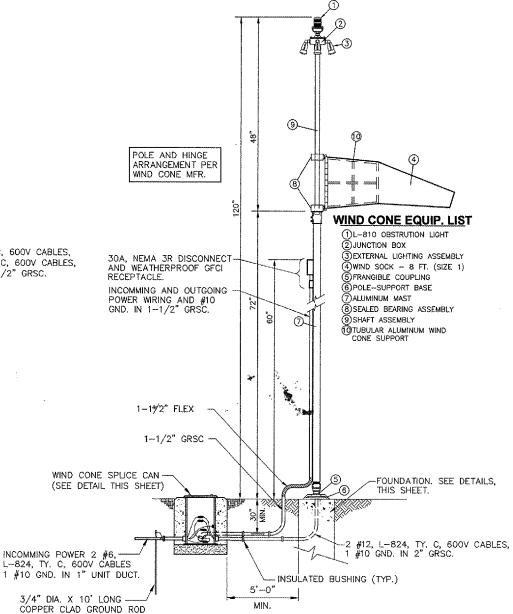

GERERAL NOTES:

WIND CONE L-806 DETAIL NOT TO SCALE

MIN. BURY 1'-0". (SEE NOTE 5)

- THE CONCRETE BASE FOR THE SPLICE CAN AND WIND CONE FOUNDATION SHALL BE TROWEL FINISHED WITH A 45° BEVELED EDGE. SLOPE TO DRAIN (610).
- 2. ALL MATERIAL, EQUIPMENT AND LABOR ARE INCIDENTAL TO WIND CONE INSTALLATION.
- 3. TO FURTHER REDUCE THE POSSIBILITY OF WATER/MOISTURE ENTRANCE INTO THE CONNECTOR BETWEEN THE CABLE AND THE FIELD ATTACHED CONNECTOR, IT IS REQUIRED THAT A HEAT SHRINKABLE TUBING WITH INTERNAL ADHESIVE BE APPLIED OVER THE ENTIRE CABLE CONNECTOR.
- THE WIND SOCK SHALL BE DAY-GLO BLAZE ORANGE NYLON FABRIC WIND CONE 8'-0" LONG OR SIMILAR.
- 5. INSTALL 1/C #6 AWG BARE COPPER GROUND JUMPER CONNECTED TO POLE BASE AND THE GROUND LUG INSIDE THE SPLICE CAN AND EXOTHERMICALLY WELDED TO GROUND ROD.

- IL. CONTRACT: LA036 IL. LETTING ITEM: 2A
- IL. PROJECT: IGQ-3565 A.I.P. PROJECT: 3-17-0121-B25

SURVEY BOOK # BOOK #

REVISIONS						
NUMBER	BY	DATE				

THIS BAR IS EQUAL TO 2

AT FULL SCALE (34X22).

SYST VILLAGE OF LANSING LANSING MUNICIPAL AIRPORT LANSING, ILLINOIS

REHABILITATE AIRFIELD LIGHTING SY ELECTRICAL DETAILS AIRFIELD LIGHTING DETAILS L-806 WIND CONE LIGHTED

MURPHY & ENGINEERS

DESIGN BY: DRAWN BY JWD CHECKED BY: AB APPROVED BY: DATE: 02 MARCH 2007

E-09

JOB No: 06297-02

SHEET 21 OF 21 SHEETS