 F.A.I. RTE.	A.I. SECTION		COUNTY		TOTAL	SHEET NO.]
90/94	2003-0311		COOL	<	976	84	ľ
STA.	STA. 12030+00 TO STA. 1243+00						
CEO 00	AD DICT NO 21	THOTC	EED	ATD	DOO IECT		ľ

62583

→②→ Z

NOTES:

- 1. SEE DRAWINGS ME-01 AND ME-02 FOR ELECTRICAL SYMBOLS AND ABBREVIATIONS.
- 2. UNLESS NOTED OTHERWISE, ALL ITEMS AND WORK SHOWN IN HEAVY LINE WEIGHT ON THIS DRAWING ARE PROPOSED NEW ITEMS OF WORK.
- 3. THE EXISTING ROADWAY LIGHTING SYSTEM SHALL REMAIN IN OPERATION UNTIL THE PROPOSED ROADWAY LIGHTING SYSTEM HAS BEEN INSTALLED, ENERGIZED, TESTED, AND ACCEPTED BY THE ENGINEER, UNLESS OTHERWISE DIRECTED BY THE ENGINEER.
- 4. SIGN SHALL BE DISCONNECTED BACK TO NEXT SPLICE, SIGN STRUCTURE AND LUMINAIRES SHALL BE REMOVED UNDER SEPARATE CONTRACT. COORDINATE WITH CONTRACTS 62694 AND 62695, NOTE: SIGN 04 TO REMAIN LIT UNTIL 79th ST. AND 87th ST. RAMPS ARE CLOSED OR AS DIRECTED BY THE ENGINEER. NOTE: PROPOSED SIGN 08 SHALL BE INSTALLED AND OPERATIONAL BEFORE EXISTING SIGN 03 IS DISCONNECTED.
- 5. PROVIDE AERIAL CABLE BETWEEN EXISTING LIGHT POLES TO PERMIT REMOVAL OF SIGN UNDER SEPARATE CONTRACT. REFER TO SHEET ME-16.

0 50' 10'


EL-12

REVISION	S	ILLINOIS DEPARTMENT OF TRANSPORTATION				
NAME	DATE	TELINOIS BEI ARTIMENT OF TRANSFORMATION				
		F.A.I. 90/94 (DAN RYAN EXPRESSWAY)				
		31st STREET TO I-57				
		J181 31KEE1 10 1-31				
		ROADWAY LIGHTING PLANS EXISTING CONDITIONS, TEMPORARY AND REMOVAL				
	1 1	CONDITIONS, LEMPORARY AND REMOVAL				

CONDITIONS, TEMPORARY AND REMOVA

SCALE: 1"=50'
DATE: OCTOBER 29, 2004

CHECKED BY: TM

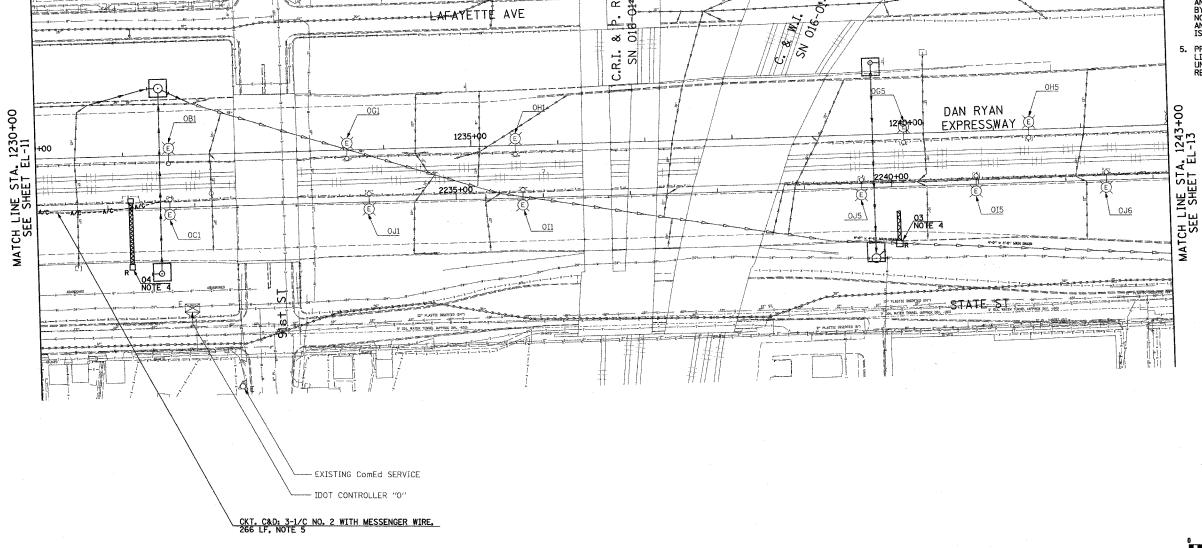

SINGH & ASSOCIATES, INC.

TEL: (312) 629-0240

CONSULTING ENGINEERS

SAM: (312) 629-8449