
F.A.I. RTE.	SECTIO	V	COUNTY		TOTAL	SHEET NO.	
90/94	2003-0311		COOK		976	229	
STA.	1334+00	TO	STA.	1347	+00		
FEO. ROA	D DIST. NO.	ILLINOIS	FED.	AID	PROJECT		
<u></u>					6	2583	

→⊕**>** Z

NOTES:

- 1. SEE DRAWINGS ME-01 AND ME-02 FOR ELECTRICAL SYMBOLS AND ABBREVIATIONS.
- 2. UNLESS NOTED OTHERWISE, ALL ITEMS AND WORK SHOWN IN HEAVY LINE WEIGHT ON THIS DRAWING ARE PROPOSED NEW ITEMS AND WORK.
- 3. THE EXISTING ROADWAY LIGHTING SYSTEM SHALL REMAIN IN OPERATION UNTIL THE PROPOSED ROADWAY LIGHTING SYSTEM HAS BEEN INSTALLED, ENERGIZED, TESTED, AND ACCEPTED BY THE ENGINEER, UNLESS OTHERWISE DIRECTED BY THE ENGINEER.
- 4. REMOVE EXISTING COMED SERVICE CABLES. REMOVE AND SALVAGE RELOCATED IDOT LIGHTING CONTROLLER.

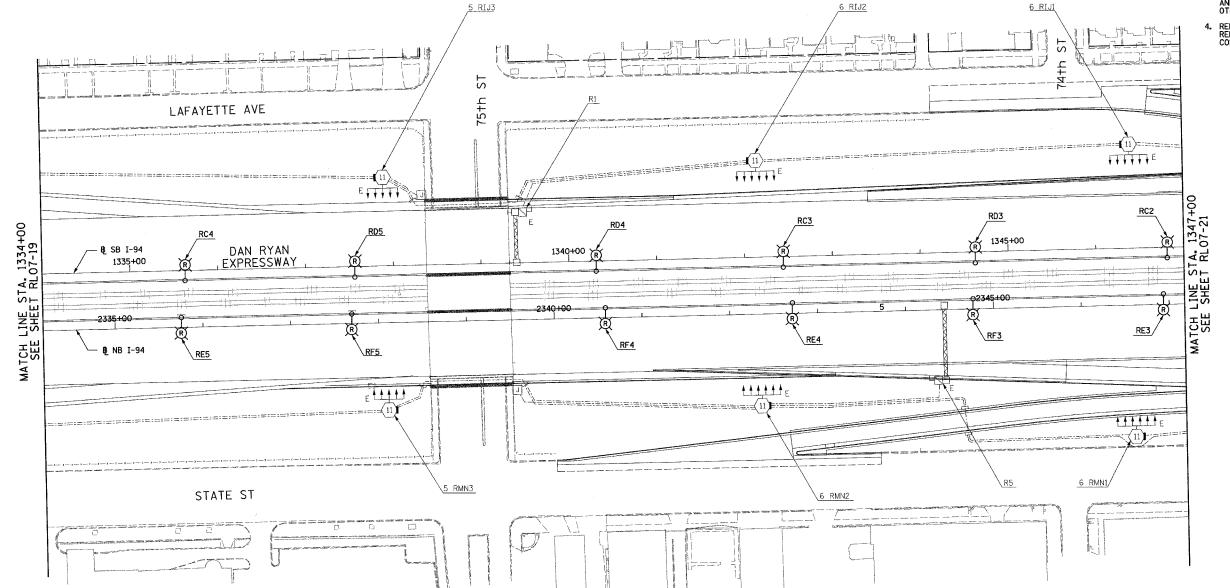

0 50' 1' 1" = 50'

RL07-20

CHECKED BY: TM

REVISIONS		Ti I	TNOTS DEP	ARTMEN'	T OF TE	TROGENAS	ATT	ON			
NAME	DATE	ILLINOIS DEPARTMENT OF TRANSPORTATION									
		F.A.I.	90/94	(DAN	RYAN	EXPR	ES:	SWAY)			
		31st STREET TO I-57									
		ROADWAY LIGHTING PLANS									
			PROPOSE	D IMP	ROVEME	NTS 200)7				
		SCALE:	1"=50"			DRAWN BY	:	VG			

01/21/05 DATE: OCTOBER 29, 2004

SINGH & ASSOCIATES, INC.
CONSULTING ENGINEERS

SINGH & ASSOCIATES, INC.
CONSULTING ENGINEERS

TAX: (312) 629-6249