
90/94 2003-0311	соок		
	COOK	976	230
STA. 1347+00	TO STA. 1360	+00	
FED. ROAD DIST. NO. IL	LINOIS FED. AID	PROJECT	

NOTES:

 $\rightarrow \bigcirc \rightarrow Z$ 

- 1. SEE DRAWINGS ME-01 AND ME-02 FOR ELECTRICAL SYMBOLS AND ABBREVIATIONS.
- UNLESS NOTED OTHERWISE, ALL ITEMS AND WORK SHOWN IN HEAVY LINE WEIGHT ON THIS DRAWING ARE PROPOSED NEW ITEMS AND WORK.
- 3. THE EXISTING ROADWAY LIGHTING SYSTEM SHALL REMAIN IN OPERATION UNTIL THE PROPOSED ROADWAY LIGHTING SYSTEM HAS BEEN INSTALLED, ENERGIZED, TESTED, AND ACCEPTED BY THE ENGINEER, UNLESS OTHERWISE DIRECTED BY THE ENGINEER.

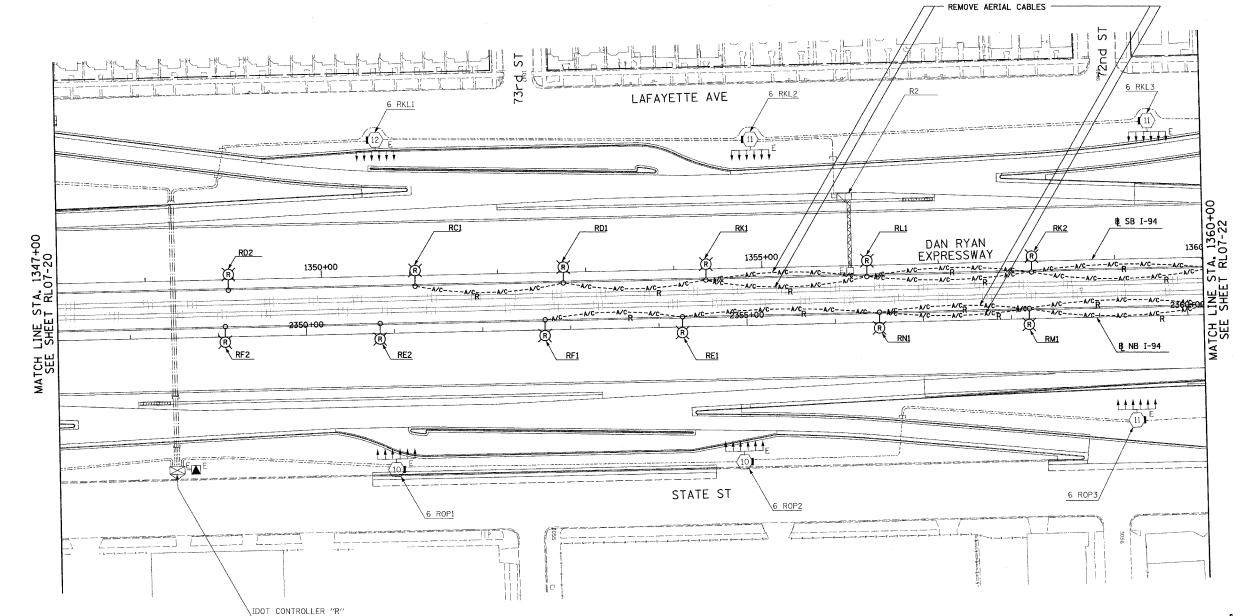

RL07-21

REVISIONS		ILLINOIS DEPARTMENT OF TRANSPORTATION	
NAME	DATE	]	1
		] F.A.I. 90/94 (DAN RYAN EXPRESSWAY) 🖟	,
		31st STREET TO I-57	!!
		J 5161 511 10 1 51	ti l
		DOADWAY : TOUTTNO DI ANG	!
		ROADWAY LIGHTING PLANS	:
		PROPOSED IMPROVEMENTS 2007	

SCALE: 1"=50' 01/21/05 DATE: OCTOBER 29, 2004

DRAWN BY: VG CHECKED BY: TM

SINGH 300 W. ADAMS ST. CHICAGO, IL 60606
SINGH & ASSOCIATES, INC. TEL: (312) 629-0240
CONSULTING ENGINEERS FAX: (312) 629-8449