
	F.A.I. RTE.	SECTION	4	COUNTY		TOTAL	SHEE NO.
	94/90	2003-031	I	COOK		976	25
	STA. 1632+00 TO STA. 1644+00						
	FED. RO	AD DIST. NO.	ILLINOIS	FED.	AID	PROJECT	

62583

**→**②→ Z

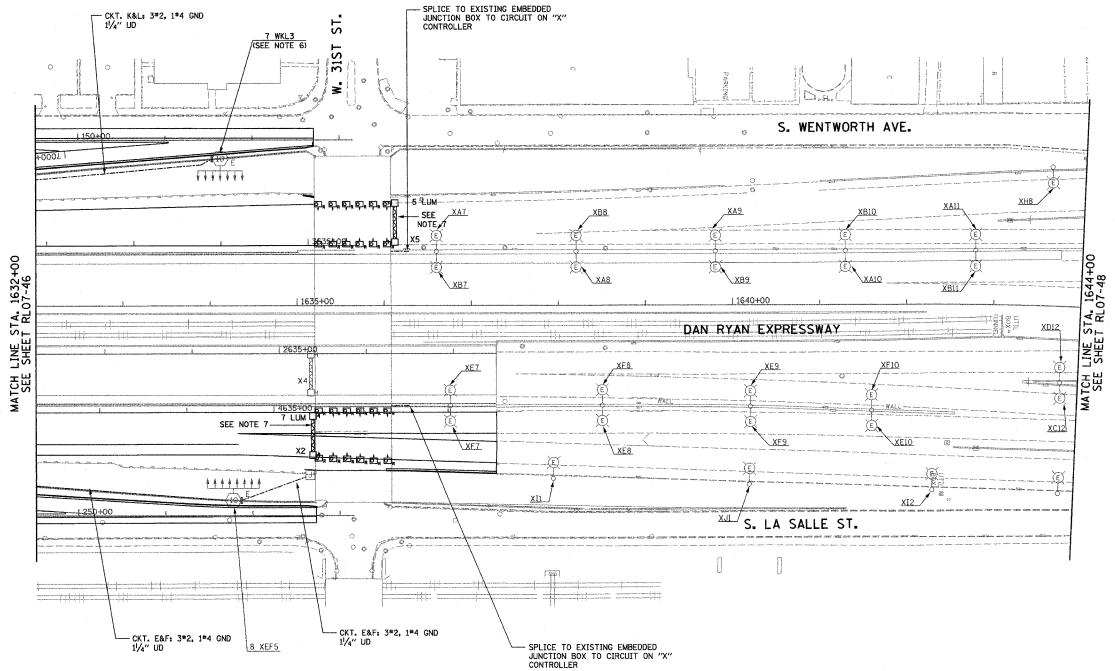

NOTES

- 1. SEE DRAWINGS ME-01 AND ME-02 FOR ELECTRICAL SYMBOLS AND ABBREVIATIONS.
- UNLESS NOTED OTHERWISE, ALL ITEMS AND WORK SHOWN IN HEAVY LINE WEIGHT ON THIS DRAWING ARE PROPOSED NEW ITEMS AND WORK.
- 3. SEE SHEET UL-07 FOR UNDERPASS LIGHTING
- 4. THE TOWERS SHALL BE CONNECTED TO THE PROPOSED LIGHTING CONTROLLERS.
- 5. REMOVE AERIAL CABLE AND WOOD POLES WHEN PERMANENT CABLE IS INSTALLED AND OPERATIONAL.
- 6. THE TEMPORARY TOWER DESIGNATIONS SHALL BE REPLACED WITH THE PERMANENT DESIGNATIONS AS INDICATED ON THIS DRAWING.
- 7. EXISTING SIGN SHALL BE REMOVED PRIOR TO THE INSTALLATION OF PROPOSED SIGN.

RL07-47

0 50' 100'

1" = 50'

SC/
DATE

ILLINOIS DEPARTMENT OF TRANSPORTATION F.A.I. 94/90 (DAN RYAN EXPRESSWAY) 31st STREET TO I-57

ROADWAY LIGHTING PLANS PROPOSED IMPROVEMENTS 2007

- SCALE: 1"=50'
DATE: OCTOBER 29, 2004

DRAWN BY: BL CHECKED BY: SM

KAM ENGINEERING, INC. CONSULTING ENGINEERS 707A Davis Road, Suite 205 Eigin, Illnois 60123-1369