


.. INCLUDED IN THE COST OF PORTLAND CEMENT CONCRETE SIDEWALK, 5 INCHES PORTLAND CEMENT CONCRETE SIDEWALK

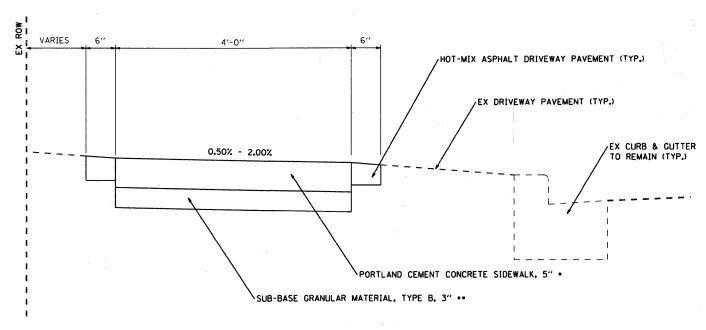

PORTLAND CEMENT CONCRETE SIDEWALK AT DRIVEWAYS

• PC CONC SIDEWALK TO BE 6" THICK ACROSS ALL DRIVEWAYS

.. INCLUDED IN THE COST OF PORTLAND CEMENT CONCRETE SIDEWALK, 5 INCHES

HOT-MIX ASPHALT MIXTURE REQUIREMENTS

MIXTURE TYPE			AC TYPE	VOIDS	
DRIVEWAYS					
HOT-MIX ASP	HALT SURFACE COURSE, MI	X "C", N50, 2"	PG 64-22	4% e 50 GYR.	

THE UNIT WEIGHT USED TO CALCULATE ALL HOT-MIX ASPHALT SURFACE MIXTURES IS 112 LBS/ SO YD

SEC Group, Inc. Frequency Penetral Backgroup Security Planning Frequency Planning Frequency Planning Frequency Frequ	USER NAME = jstrzalka	DESIGNED	-	JJS	REVISED	-	
	Engineering Surveying		DRAWN	-	JJS	REVISED	-
	Landscape Architecture	PLOT SCALE = 1:20	CHECKED	-	JLP	REVISED	-
	Illinois * Texas * Georgia www.secgroupinc.com	PLOT DATE = 4/1/2009	DATE	-	4/1/09	REVISED	*

PROPOSED TYPICAL SECTIONS SCALE: 1:20

COUNTY TOTAL SHEET NO.

LAKE 40 4 SECTION 08-00086-00-SW CONTRACT NO. 63166

VILLAGE OF MUNDELEIN

SHEET NO. 1 OF 1 SHEETS STA. NA TO STA. NA