
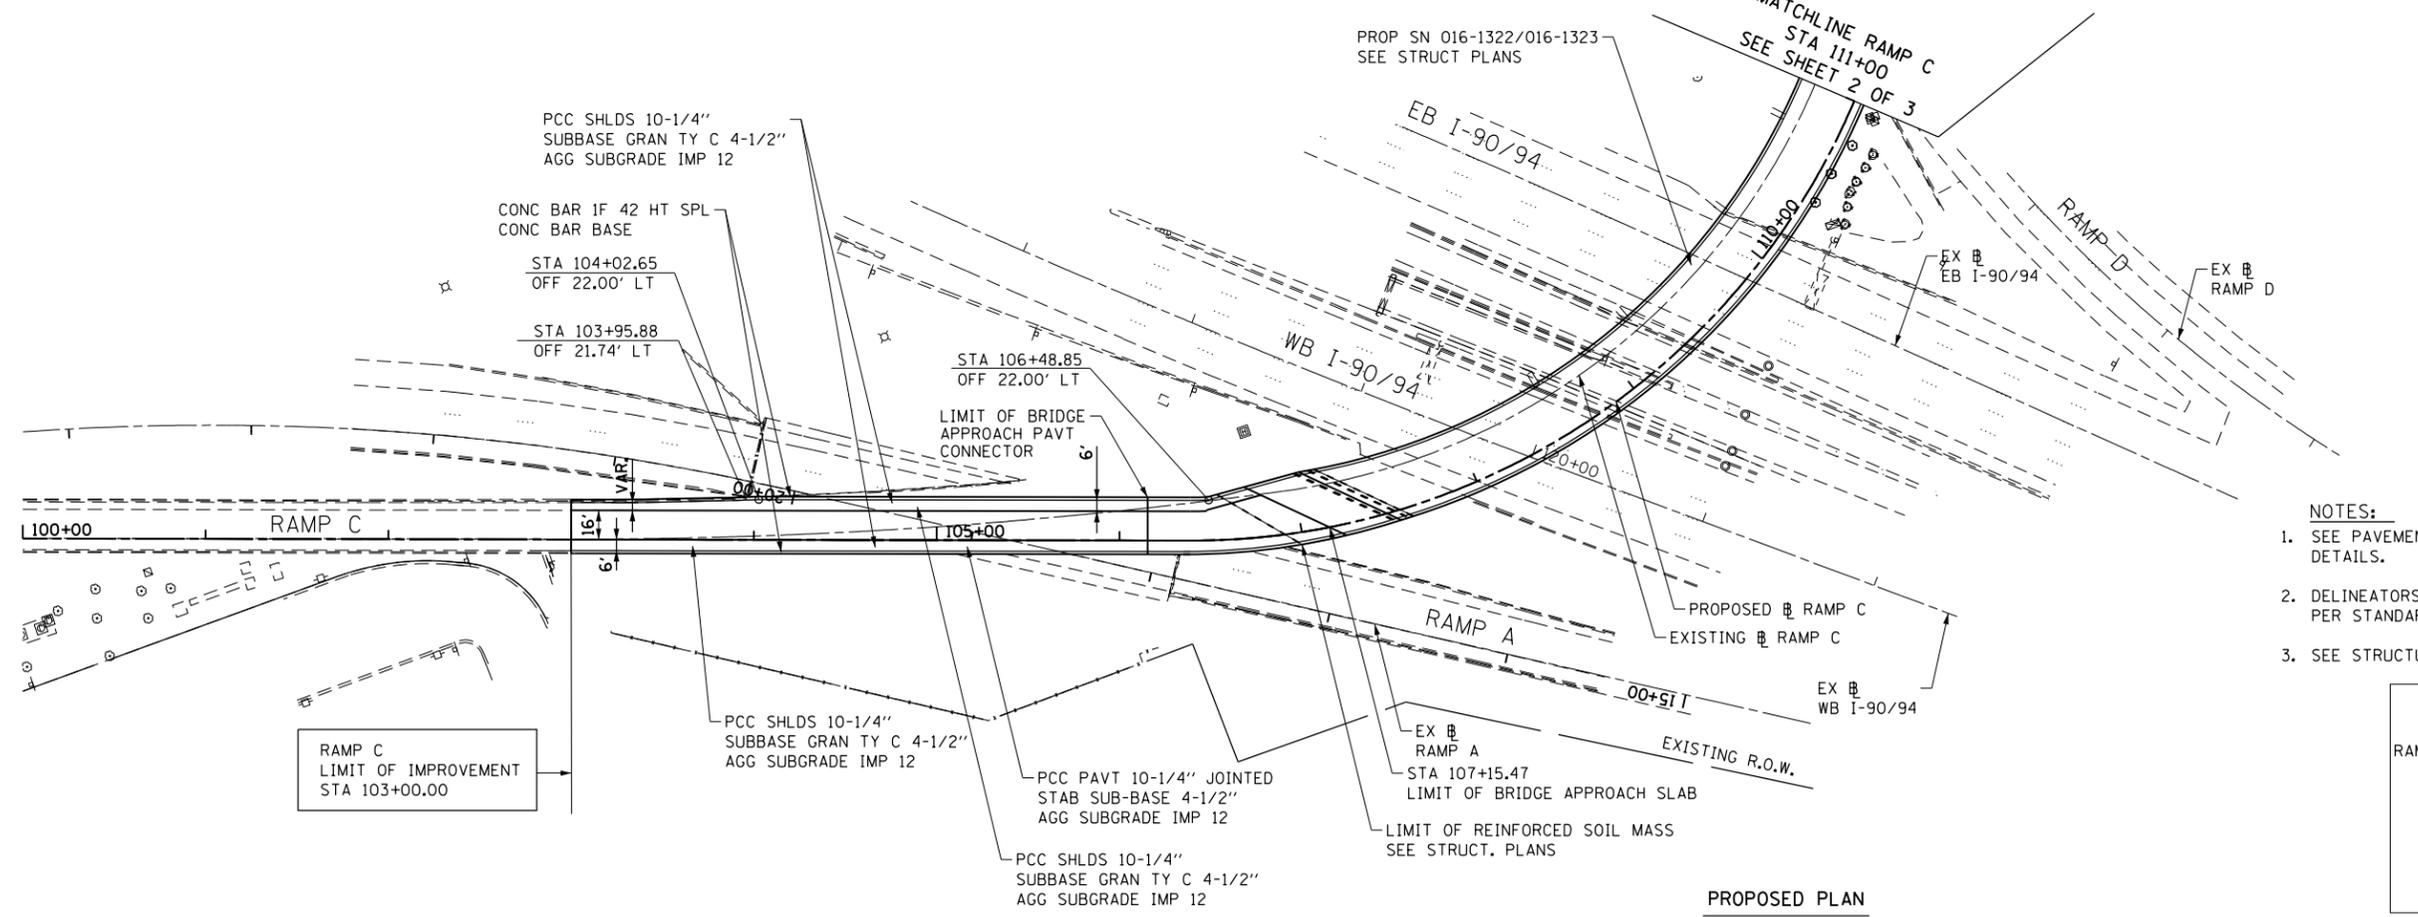


LEGEND - REMOVAL

-  PAVEMENT REMOVAL
-  MEDIAN / SHOULDER REMOVAL
-  LINEAR REMOVAL
-  TREE REMOVAL (SIZE IN UNITS)
-  TREE TRUNK PROTECTION


NOTES:

1. REMOVAL OF PROTECTIVE PCC SLAB TO BE PAID FOR AS PAVEMENT REMOVAL.
2. SEE DRAINAGE AND UTILITY PLANS FOR REMOVAL OF DRAINAGE RELATED ITEMS.
3. REMOVAL OF SIGN PANEL ASSEMBLY, TYPE A OR TYPE B INCLUDES THE REMOVAL OF THE EXISTING SIGN PANEL.
4. SEE EXISTING LIGHTING PLAN FOR REMOVAL OF EXISTING LIGHTING UNITS.

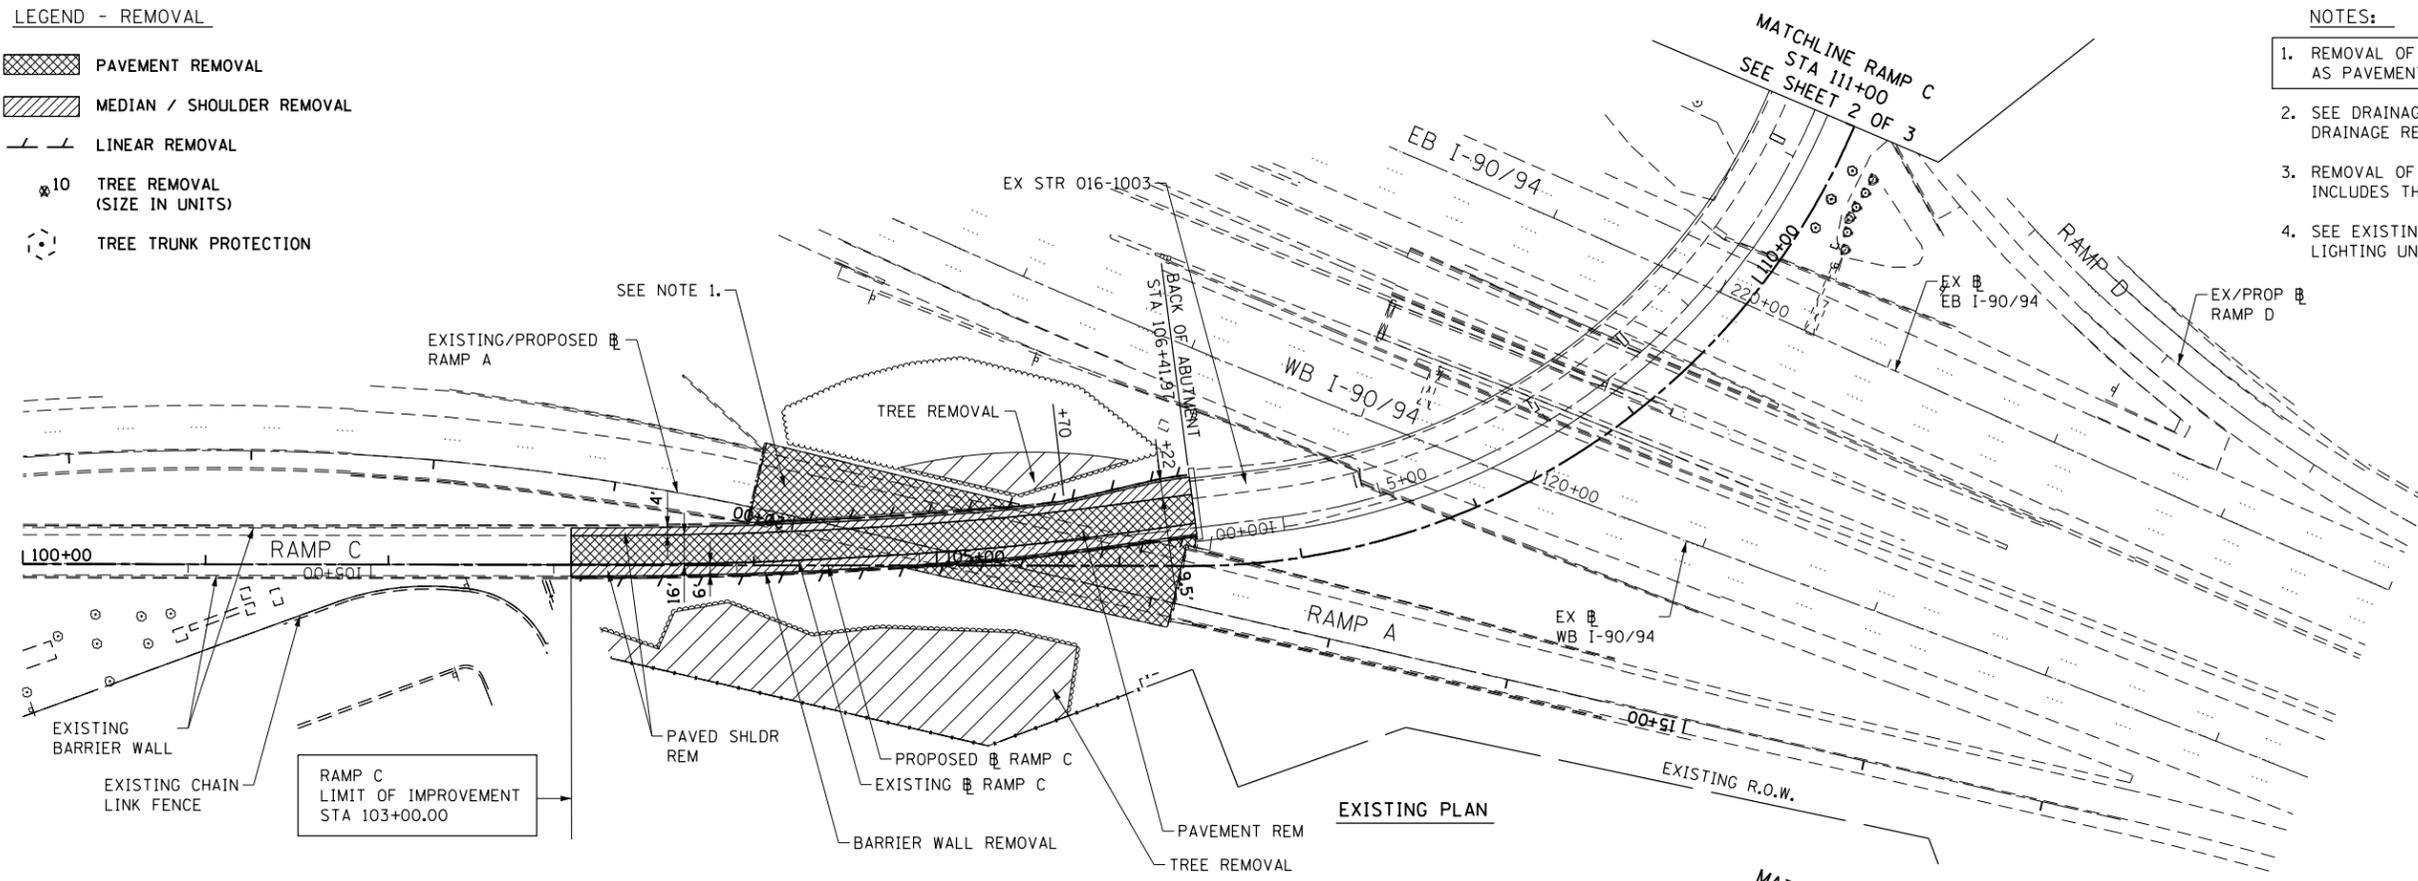

NOTES:

1. SEE PAVEMENT JOINTING PLAN FOR ADDITIONAL DETAILS.
2. DELINEATORS SHALL BE PLACED ALONG THE RAMPS PER STANDARD 635001 SPACED 100 FT ON CENTERS.
3. SEE STRUCTURAL SHEETS FOR ANCHORAGE SLAB DETAILS.

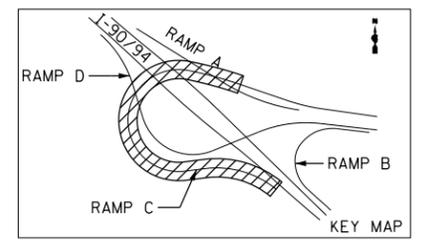

FILE NAME = I:\7000 - 194 at Ohio Street\CADD\CADD_SHEET\SD160663-RAMP1.dgn

COLLINS ENGINEERS

USER NAME = r9e11
 PLOT SCALE = 100.000000' / in.
 PLOT DATE = 3/25/2013

DESIGNED -
 DRAWN -
 CHECKED -
 DATE -

REVISED -
 REVISED -
 REVISED -
 REVISED -

**STATE OF ILLINOIS
 DEPARTMENT OF TRANSPORTATION**

**RAMP C
 EXISTING AND PROPOSED PLAN**

SCALE: SHEET NO. OF SHEETS STA. TO STA.

F.A.I. RTE.	SECTION	COUNTY	TOTAL SHEETS	SHEET NO.
90/94	0303-474HB-R	COOK	368	41
CONTRACT NO. 60F63				
FED. ROAD DIST. NO. 1 ILLINOIS FED. AID PROJECT				