
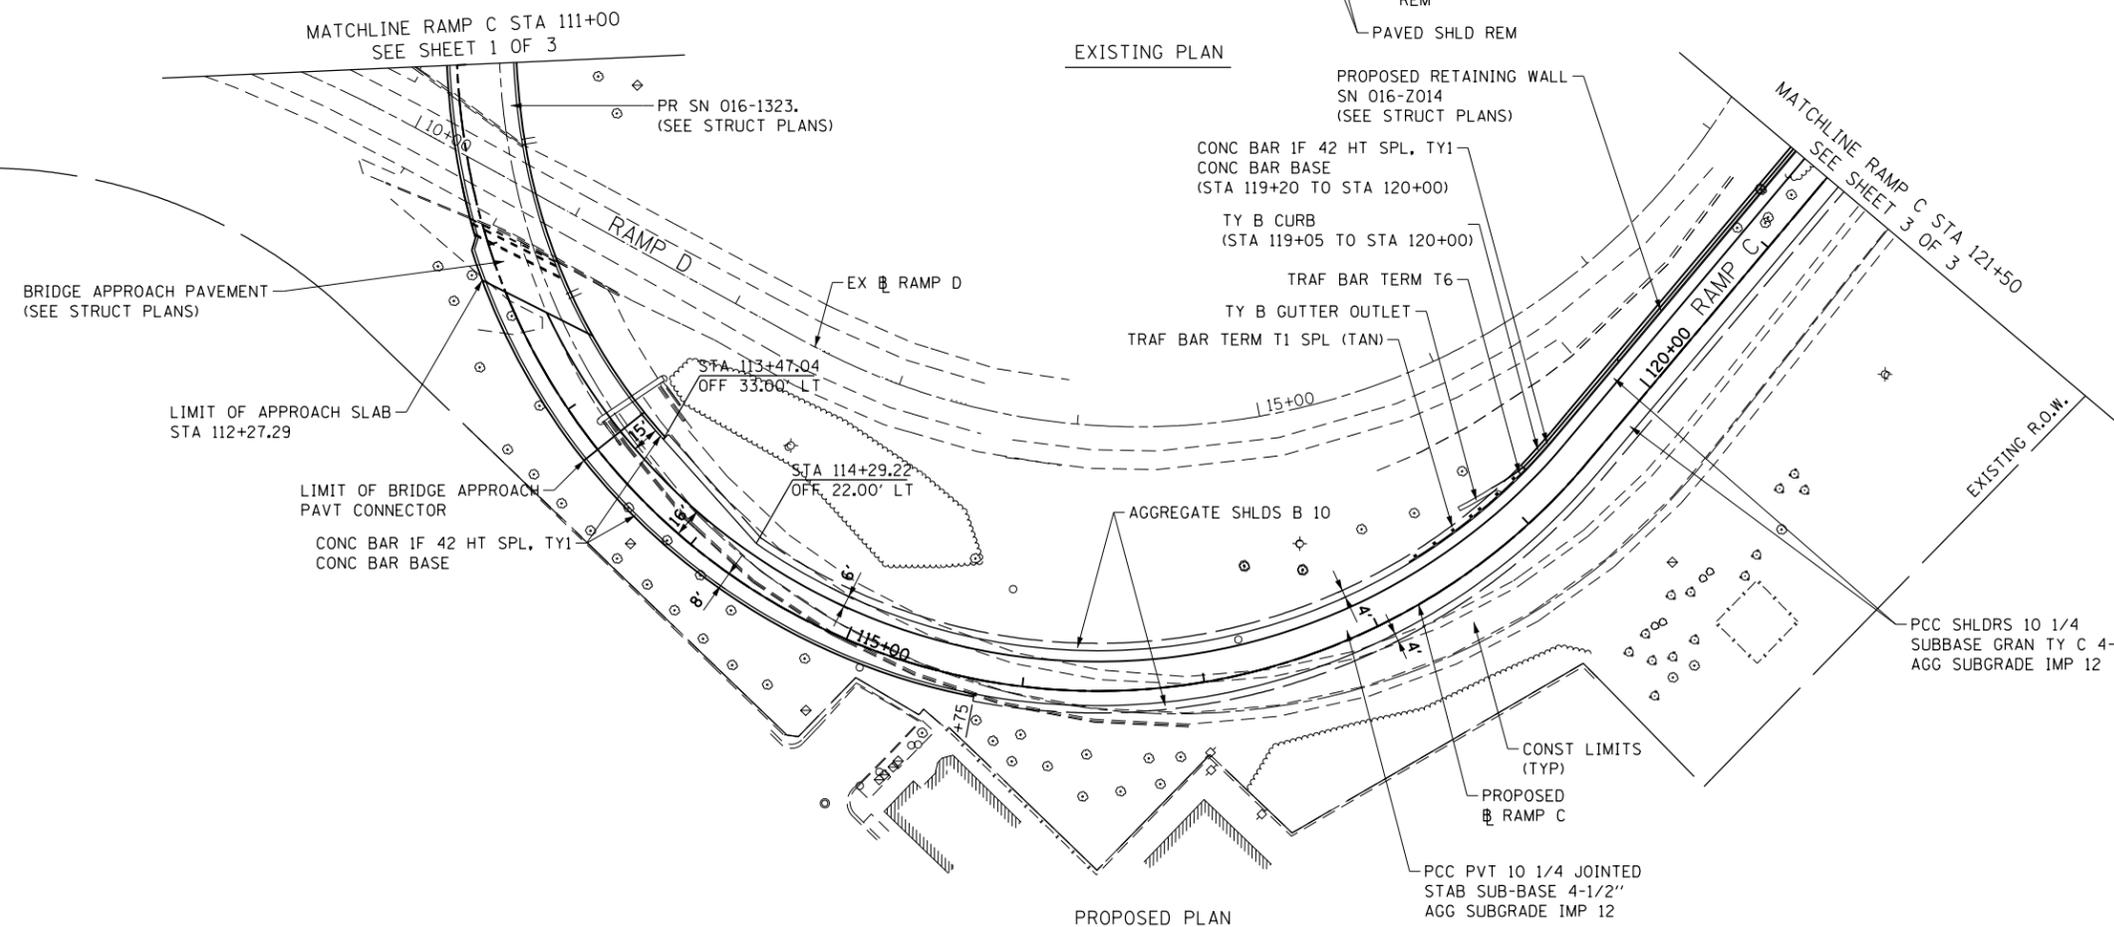


**LEGEND - REMOVAL**

-  PAVEMENT REMOVAL
-  MEDIAN / SHOULDER REMOVAL
-  LINEAR REMOVAL
-  TREE REMOVAL (SIZE IN UNITS)
-  TREE TRUNK PROTECTION


**NOTES:**

1. SEE STRUCTURE PLANS FOR REMOVALS ON STRUCTURE.
2. SEE DRAINAGE AND UTILITY PLANS FOR REMOVAL OF DRAINAGE RELATED ITEMS.
3. REMOVAL OF SIGN PANEL ASSEMBLY, TYPE A OR TYPE B INCLUDES THE REMOVAL OF THE EXISTING SIGN PANEL.
4. SEE EXISTING LIGHTING PLAN FOR REMOVAL OF EXISTING LIGHTING UNITS.
5. THE CONTRACTOR SHALL BE ADVISED THE INTERCHANGE CONTAINS AN EXISTING IRRIGATION SYSTEM. CARE SHALL BE TAKEN NOT TO DISTURB THE VALVES, PIPES, FITTINGS, ETC. OUTSIDE THE LIMITS OF CONSTRUCTION DURING REMOVAL OPERATIONS. SEE IRRIGATION PLANS FOR RESTORATION DETAILS.

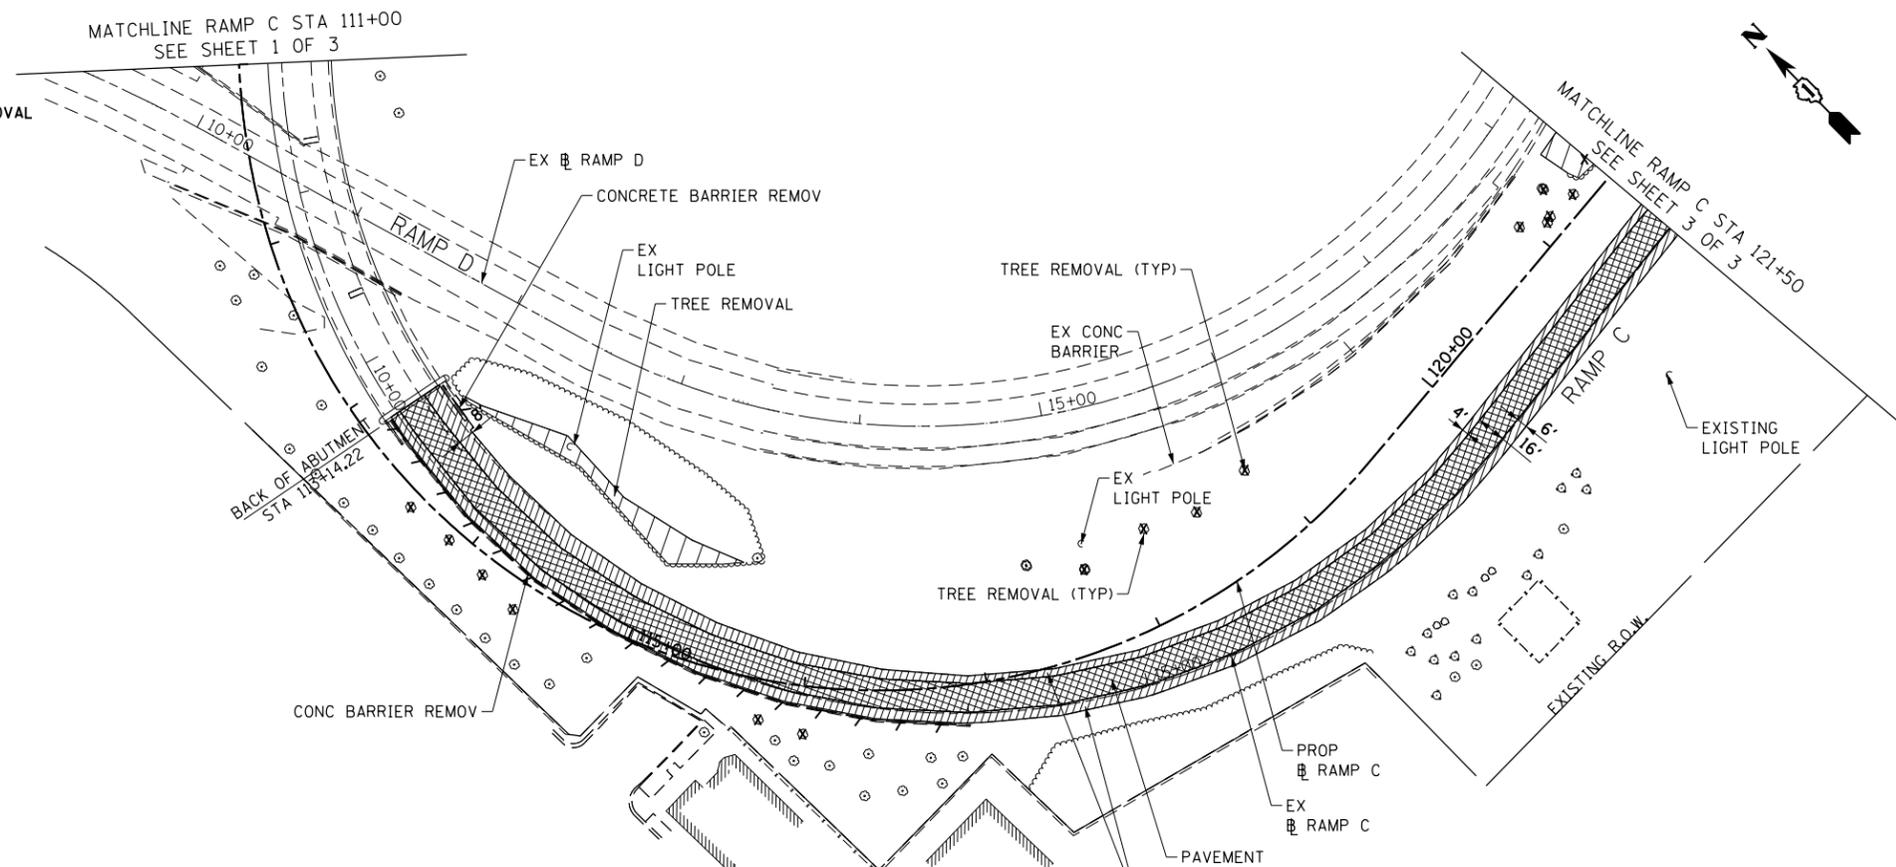

**NOTES:**

1. SEE PAVEMENT JOINTING PLAN FOR ADDITIONAL DETAILS.
2. DELINEATORS SHALL BE PLACED ALONG THE RAMPS PER STANDARD 635001 SPACED 100 FT ON CENTERS.
3. SEE STRUCTURAL PLANS FOR ANCHORAGE SLAB DETAILS.

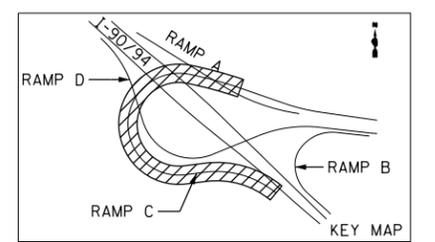

FILE NAME = I:\7000 - 194 at Ohio Street\CADD\CADD\_SHEETS\SD1606\63-RMP2.dgn

**COLLINS ENGINEERS**

USER NAME = r9e11	DESIGNED -	REVISED -
PLOT SCALE = 100.000000' / in.	DRAWN -	REVISED -
PLOT DATE = 3/25/2013	CHECKED -	REVISED -
	DATE -	REVISED -

**STATE OF ILLINOIS  
DEPARTMENT OF TRANSPORTATION**

**RAMP C  
EXISTING AND PROPOSED PLAN**

SCALE: SHEET NO. OF SHEETS STA. TO STA.

F.A.I. RTE. 90/94	SECTION 0303-474HB-R	COUNTY COOK	TOTAL SHEETS 368	SHEET NO. 42
CONTRACT NO. 60F63				
FED. ROAD DIST. NO. 1 ILLINOIS FED. AID PROJECT				