



N

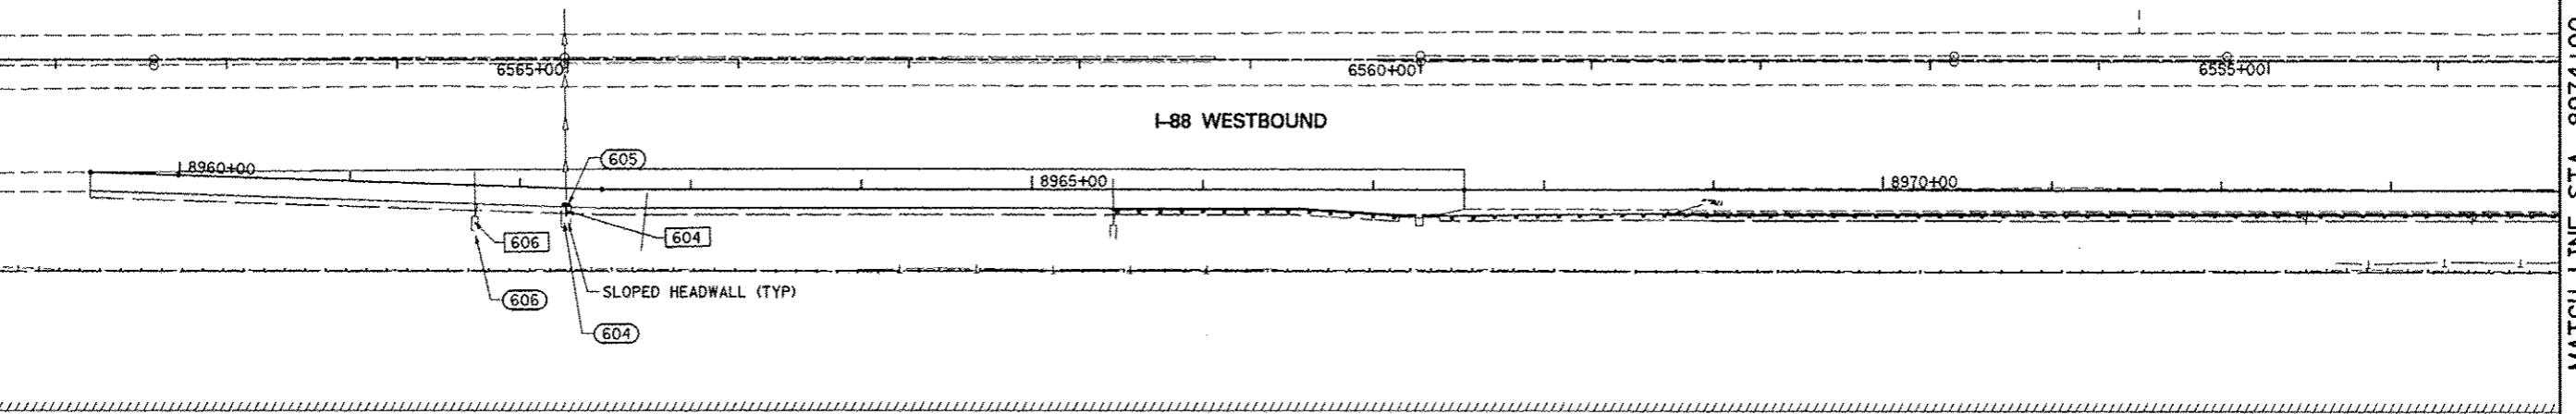

MATCH LINE STA. 8974+00

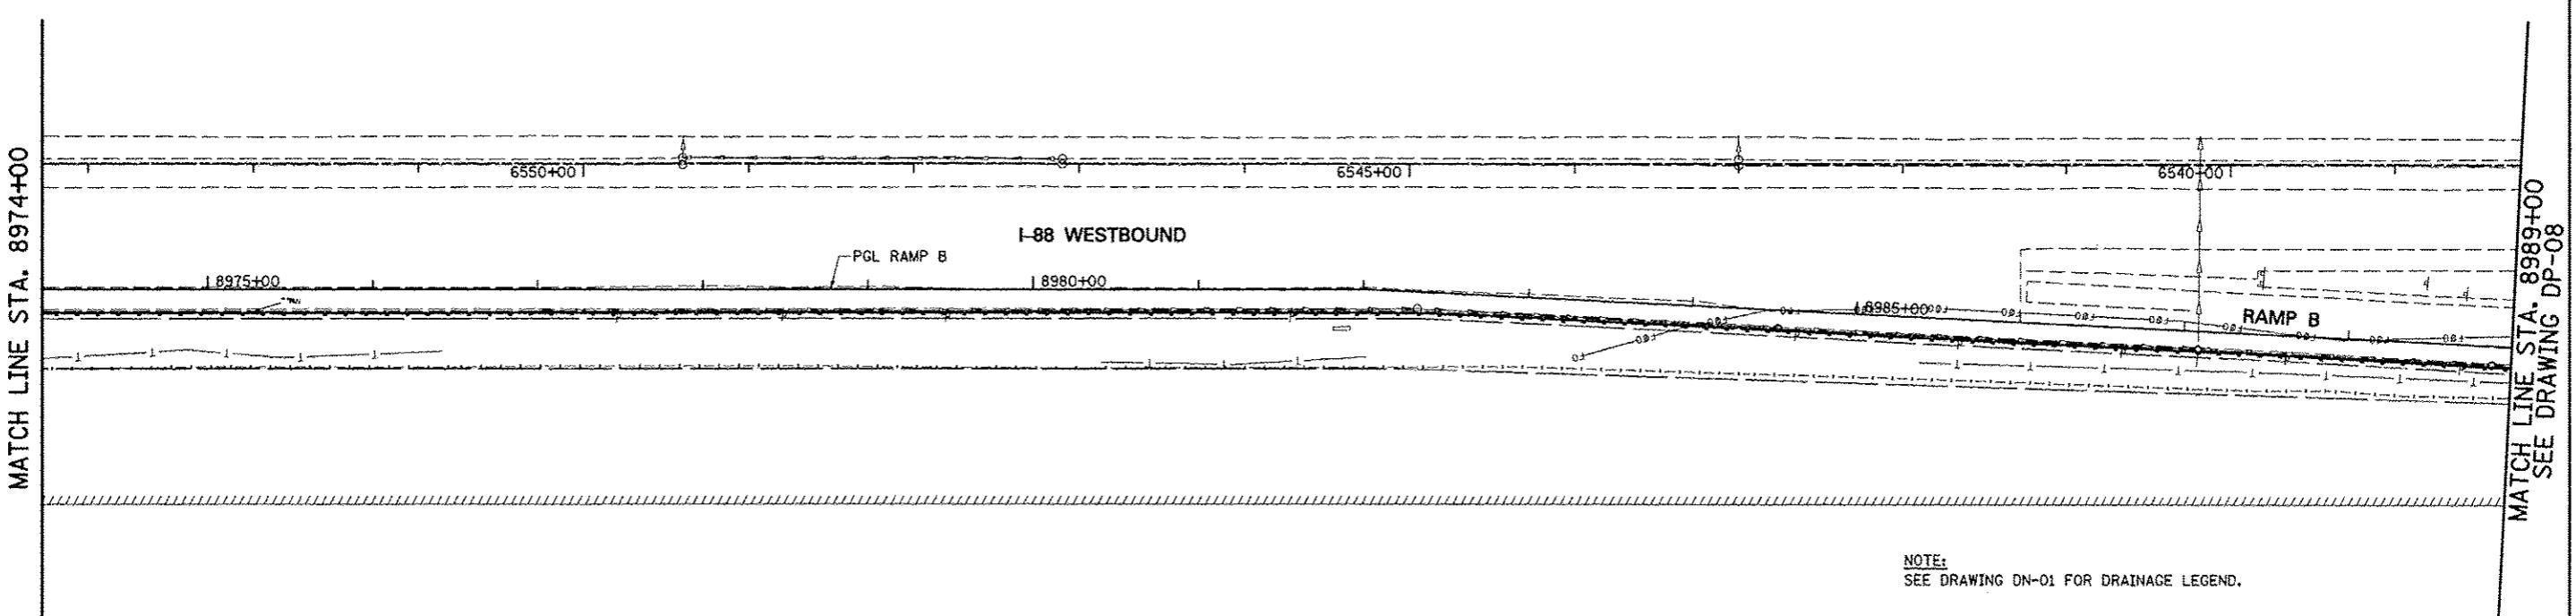

MATCH LINE STA. 8974+00
SEE DRAWING DP-08

NOTE:
SEE DRAWING DN-01 FOR DRAINAGE LEGEND.

0 50' 100' 150' 200'
SCALE IN FEET

FILE NAME: #FILE#	USER NAME: #USER#	DESIGNED: PJO	REVISED: -	STATE OF ILLINOIS DEPARTMENT OF TRANSPORTATION	PROPOSED DRAINAGE PLAN - RAMP B			F.A.P. RTE: 338	SECTION: (112 & 113) WRS-5	COUNTY: DUPAGE	TOTAL SHEETS: 963	HEET NO. 346
PLOT SCALE: #SCALE#	CHECKED: JCM	REVISED: -				DP-08	CONTRACT NO. 60131					
PLDT DATE: #DATE#	DATE: 10/15/2012	REVISED: -	PROPOSED DRAINAGE PLAN - RAMP B			SCALE: 1''=50'	SHEET NO. 9 OF 12 SHEETS	STA. BEGIN	TO STA. 8989+00	ILLINOIS FED. AID PROJECT		