
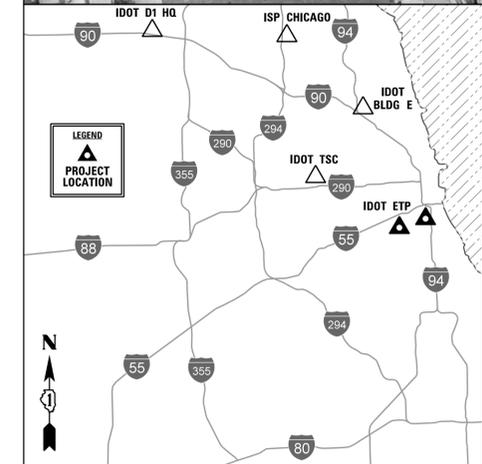
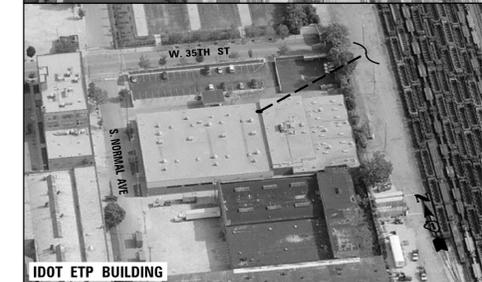



SCOPE OF WORK

1. INSTALL NEW MICROWAVE LINK BETWEEN IDOT ETP AND THE PROPOSED COMMUNICATIONS CABINET ON WEST SIDE OF DAN RYAN SOUTH OF 33RD ST. CONTRACTOR SHALL COORDINATE, FURNISH AND INSTALL ALL REQUIRED EQUIPMENT FOR IDOT ETP TO VIEW VIDEO FROM UP TO 4 OF ANY OF IDOT'S TRAFFIC CAMERAS THRU LINK.
2. IDOT HAS PERFORMED A FREQUENCY INTERFERENCE FIELD TEST FOR AN UNLICENSED 5 GHz FREQUENCY AND DETERMINED THAT INTERFERENCE LEVEL IS ACCEPTABLE.

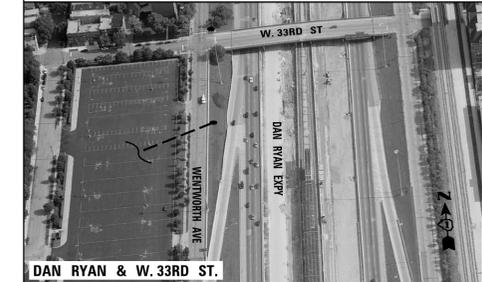


CHRISTOPHER B. BURKE ENGINEERING, LTD.
 9575 W. Higgins Road, Suite 600
 Rosemont, Illinois 60018
 (847) 823-0500

F.A. RTE.	SECTION	COUNTY	TOTAL SHEETS	SHEET NO.
	2009-0871	COOK	20	5
			CONTRACT NO. 60134	
ILLINOIS FED. AID PROJECT				

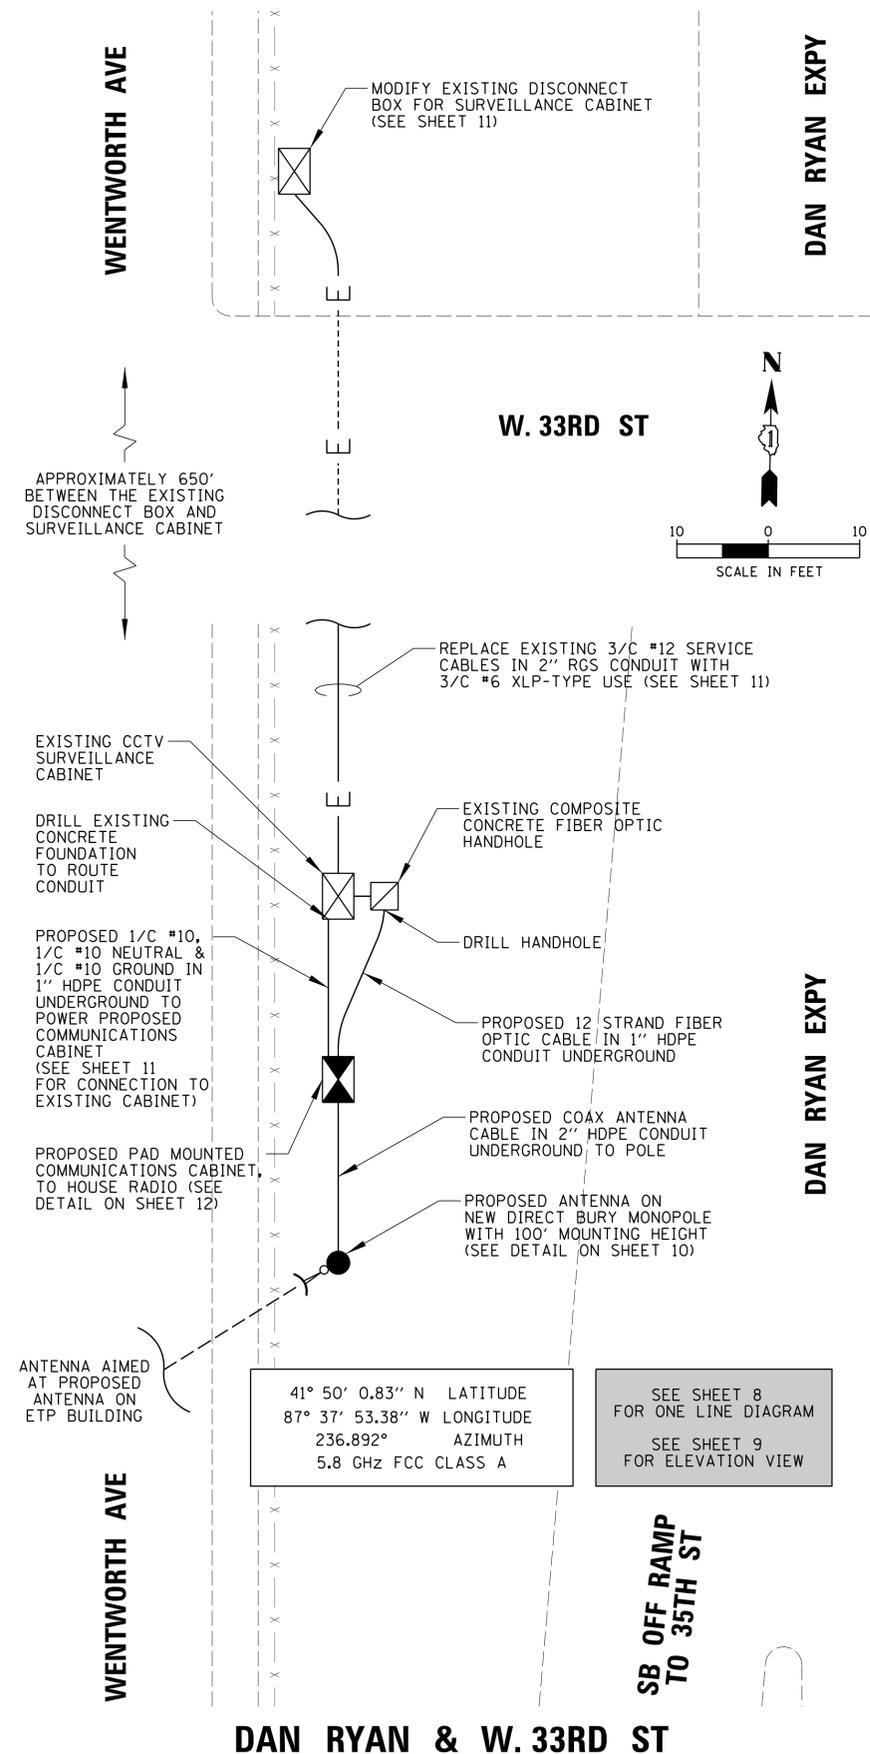

41° 50' 0.83" N LATITUDE
 87° 37' 53.38" W LONGITUDE
 236.892° AZIMUTH
 5.8 GHz FCC CLASS A

SEE SHEET 8 FOR ONE LINE DIAGRAM
 SEE SHEET 9 FOR ELEVATION VIEW

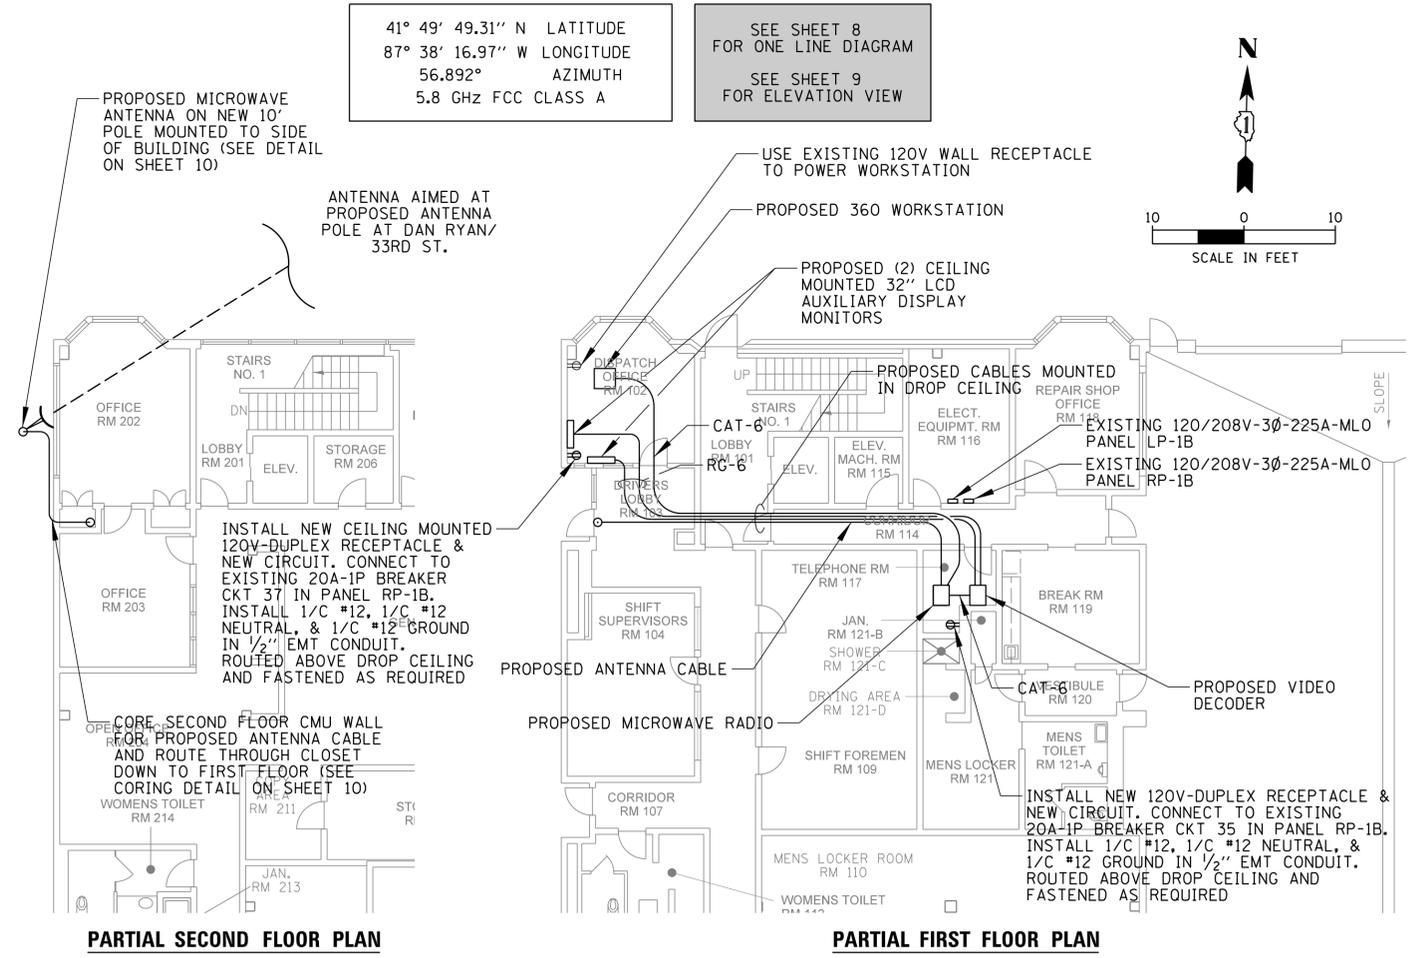

41° 49' 49.31" N LATITUDE
 87° 38' 16.97" W LONGITUDE
 56.892° AZIMUTH
 5.8 GHz FCC CLASS A

SEE SHEET 8 FOR ONE LINE DIAGRAM
 SEE SHEET 9 FOR ELEVATION VIEW

IDOT ETP BUILDING

FILE NAME =	USER NAME =	DESIGNED	REVISED
N:\idot\090122\Mech\090122_05_IDOTETP_PL	odericco	AJD	-
		DRAWN	REVISED
		KWB	-
		CHECKED	REVISED
		JPC	-
		DATE	REVISED
		3/21/2013	-

STATE OF ILLINOIS
 DEPARTMENT OF TRANSPORTATION

ITS CENTER-TO-CENTER INTEGRATION PROJECT
 IDOT ETP BUILDING / DAN RYAN & W. 33RD ST
 SCALE: 1" = 10' SHEET NO. OF SHEETS STA. TO STA.