



IDOT ETP BUILDING (35TH & NORMAL) DAN RYAN EXPY / W. 33TH ST.

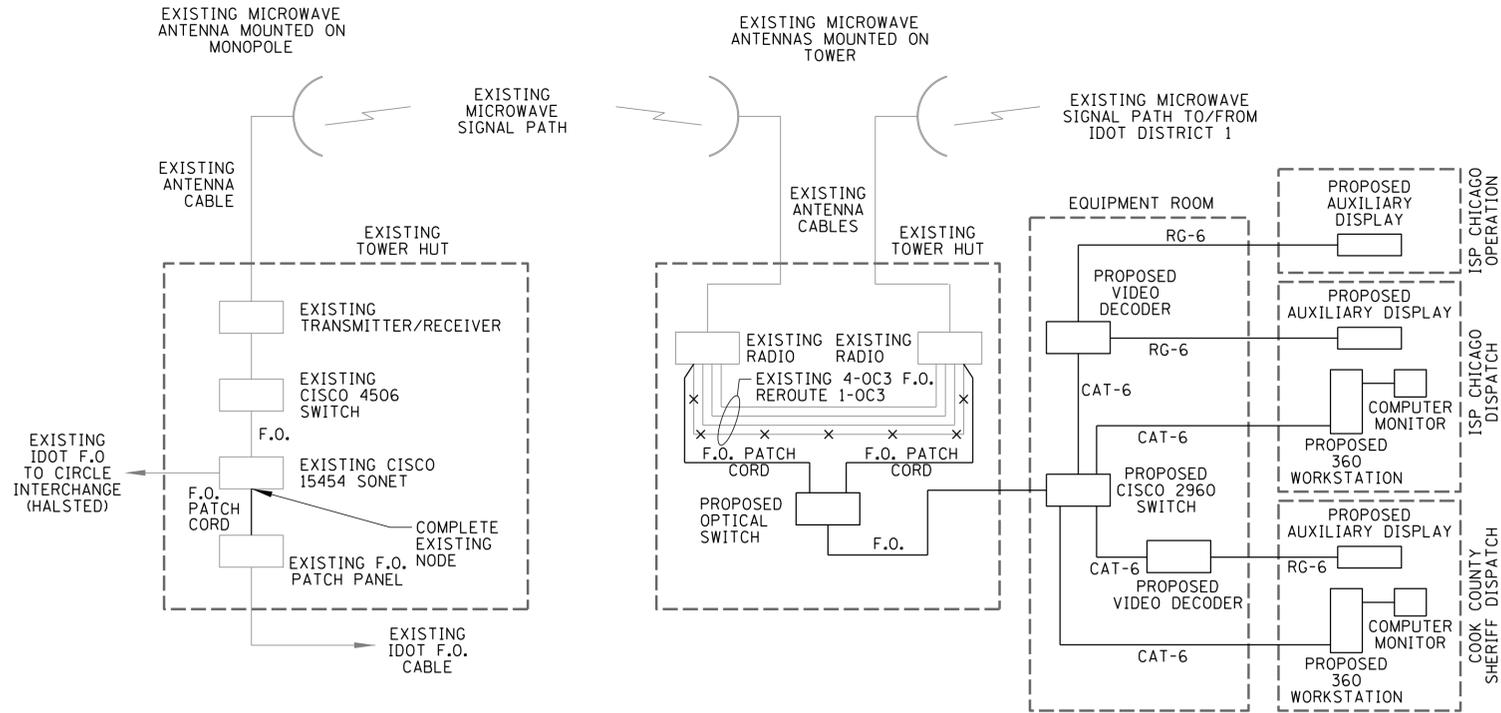

BUILDING E (KENNEDY / EDENS EXPY) ISP CHICAGO / COOK COUNTY SHERIFF

EXISTING CONDITIONS SHOWN IN HALF TONE
PROPOSED CONDITIONS SHOWN IN BOLD

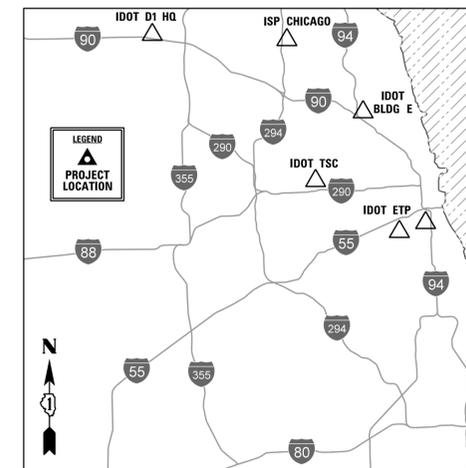

CHRISTOPHER B. BURKE ENGINEERING, LTD.
9575 W. Higgins Road, Suite 600
Rosemont, Illinois 60018
(847) 823-0500

| | | | |
|--|-----------------------|-----------------------|-----------|
| FILE NAME = | USER NAME = omerico | DESIGNED <i>AJD</i> | REVISED - |
| N:\Idot\090122\Mech\090122.08_OneLine.LD | T_01.sht | DRAWN <i>KWB</i> | REVISED - |
| | PLOT SCALE = 10' | CHECKED <i>JPC</i> | REVISED - |
| | PLOT DATE = 3/22/2013 | DATE <i>3/21/2013</i> | REVISED - |

**STATE OF ILLINOIS
DEPARTMENT OF TRANSPORTATION**

**ITS CENTER-TO-CENTER INTEGRATION PROJECT
ONE LINE DIAGRAMS**

SCALE: N.T.S. SHEET NO. OF SHEETS STA. TO STA.

| | | | | |
|--------------------|-----------|--------|---------------------------|-----------|
| F.A. RTE. | SECTION | COUNTY | TOTAL SHEETS | SHEET NO. |
| | 2009-0871 | COOK | 20 | 8 |
| CONTRACT NO. 60134 | | | ILLINOIS FED. AID PROJECT | |