
RTE. SECTION COUNTY TOTAL SHEETS NO. WILL STA. TO STA. FEO. ROAD DIST. NO. 1 ILLINOIS FED. AID PROJECT

\* (26, 26HB-1 & 114) R-2 CONTRACT NO. 60363

**→**□→ Z

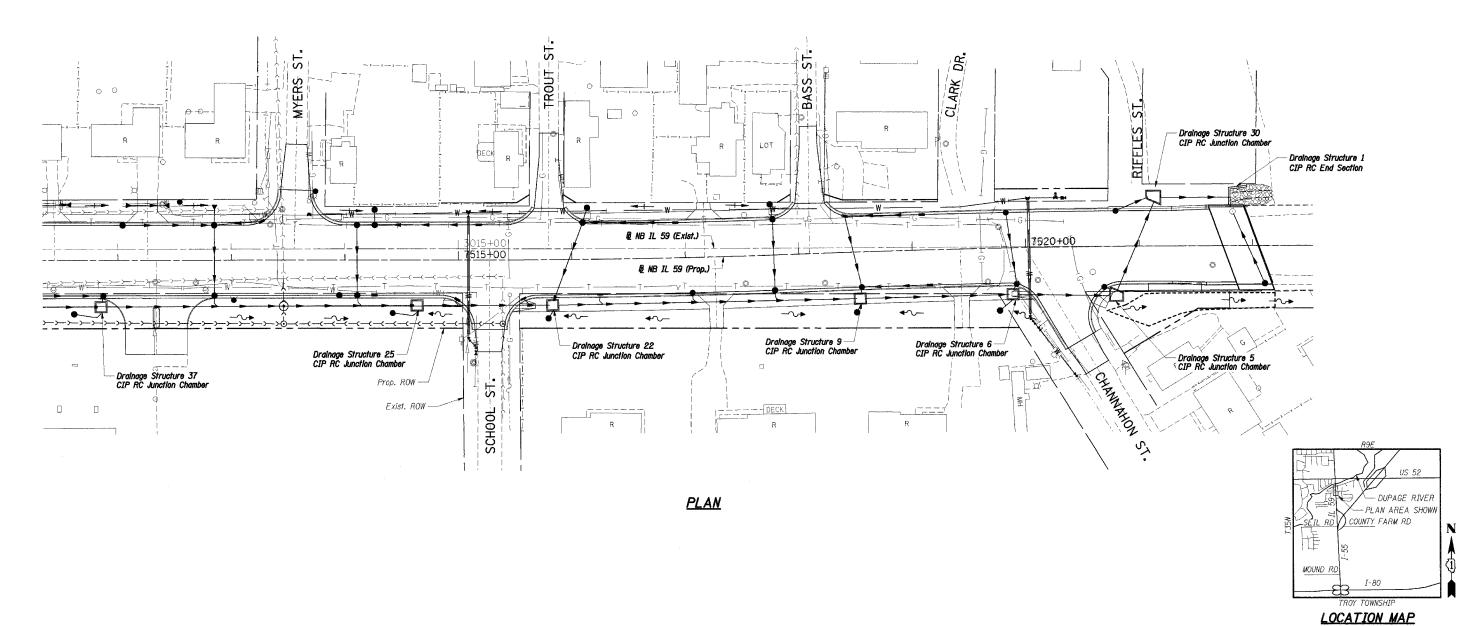

**DESIGN SPECIFICATIONS:**2002 AASHTO Standard Specifications for Highway Bridges

### DESIGN LOADING:

Live Load: HS20-44
Earth Pressure = 40 pcf Equivalent Fluid Weight
Live Load Surcharge = 2'
Earth Mass = 120 pcf

Concrete, f'c = 3,500 psi Reinforcement, fy = 60,000 psi

GENERAL NOTES:
1. Reinforcement bars shall conform to the requirements of ASTM A 706 Gr 60 (IL Modified). See Special Provisions.

# TOTAL BILL OF MATERIAL

Item	Unit	Total
Porous Granular Embankment (Special)	Cu Yd	36
Structure Excavation	Cu Yd	646
Rock Excavation for Structures	Cu Yd	88.5
Concrete Structures	Cu Yd	143.5
Furnishing and Erecting Structural Steel	lbs	1,640
Reinforcement Bars	lbs	34,620
Geocomposite Wall Drain	Sq Ft	243
Frames, Type 1	Each	7
Lids, Type I, Closed Lid	Each	7
Temporary Soil Retention System	Sq Ft	583

### INDEX OF SHEETS:

DS-1 DRAINAGE STRUCTURES; OVERALL PLAN I DS-2 DRAINAGE STRUCTURES; OVERALL PLAN II DS-3 DRAINAGE STRUCTURE 1; PLAN AND DETAILS

DS-4 DRAINAGE STRUCTURE 1; DETAILS

DS-5 DRAINAGE STRUCTURE 5; PLAN AND DETAILS

DS-6 DRAINAGE STRUCTURES 6, 9, 22, 25 AND 37; PLAN AND DETAILS
DS-7 DRAINAGE STRUCTURES 6, 9, 22, 25 AND 37; DETAILS AND BILLS OF MATERIAL

DS-8 DRAINAGE STRUCTURE 30; PLAN AND DETAILS

DS-9 DRAINAGE STRUCTURES 203 & 204; PLAN AND DETAILS

DS-10 TEMPORARY SOIL RETENTION SYSTEM

## LEGEND:

— Prop. Storm Sewer, See Note 2

Prop. Manhole, See Note 2

Prop. Junction Chamber

Prop. Rip Rap, See Note 2

Exist. Storm Sewer

Exist. Manhole

---- T ---- Exist. Telephone Line

— G ⊢ Exist, Gas Main Line

SHT. DS-1 OF DS-11

REVISIONS NAME DATE

Notes:
1. Work this sheet with Shts. DS-2 thru DS-II. 2. See Drainage Plans for details.

ILLINOIS DEPARTMENT OF TRANSPORTATION FAI 55 AT FAP 338 ILLINOIS ROUTE 59 SECTION: (26, 26HB-1 & 114) R-2

> DRAINAGE STRUCTURES OVERALL PLAN I

DRAWN BY: BGK

TENG

DATE: 03/14/08

CHECKED BY: TMH TENG & ASSOCIATES, INC. ENGINERESARCHITECTSPLANNERS 205 N. MICHIGAN AVE. CHICAGO, IL 8080 TELEPHONE 312816-0000