
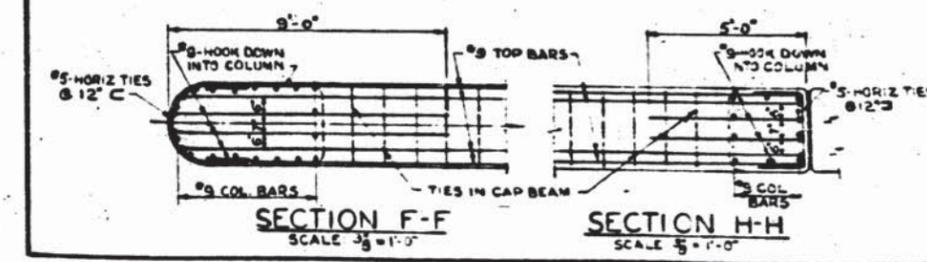
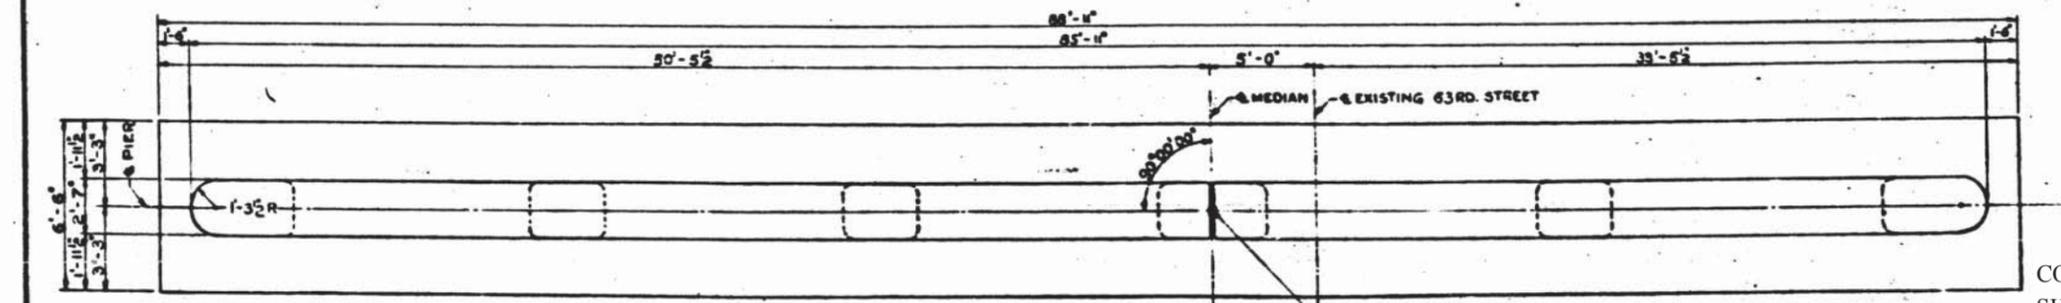
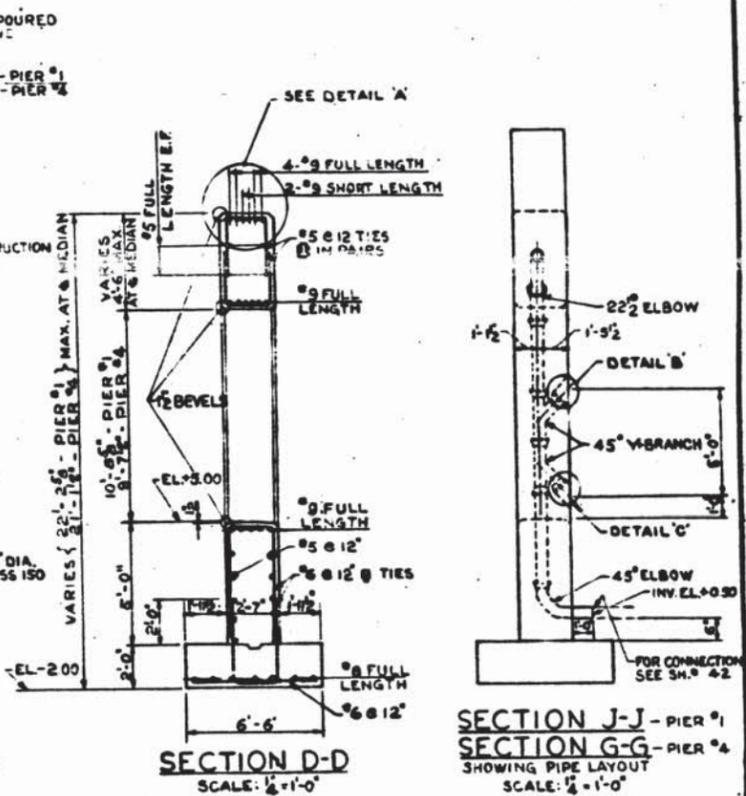
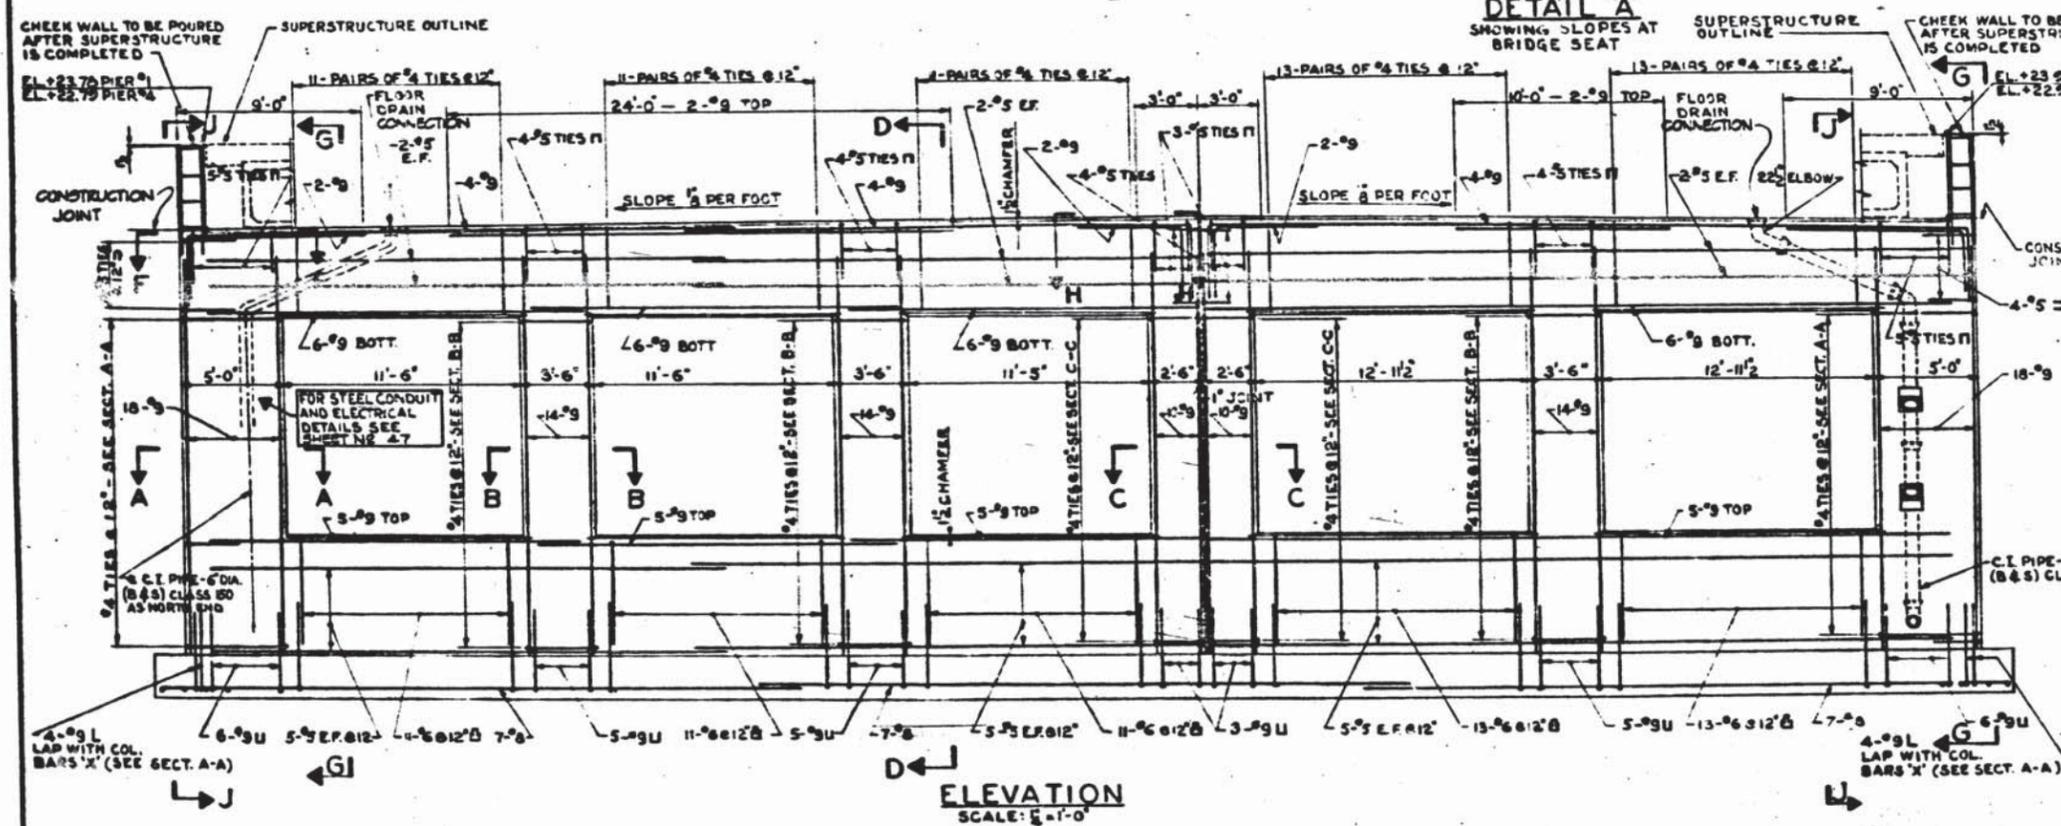


FOR INFORMATION ONLY

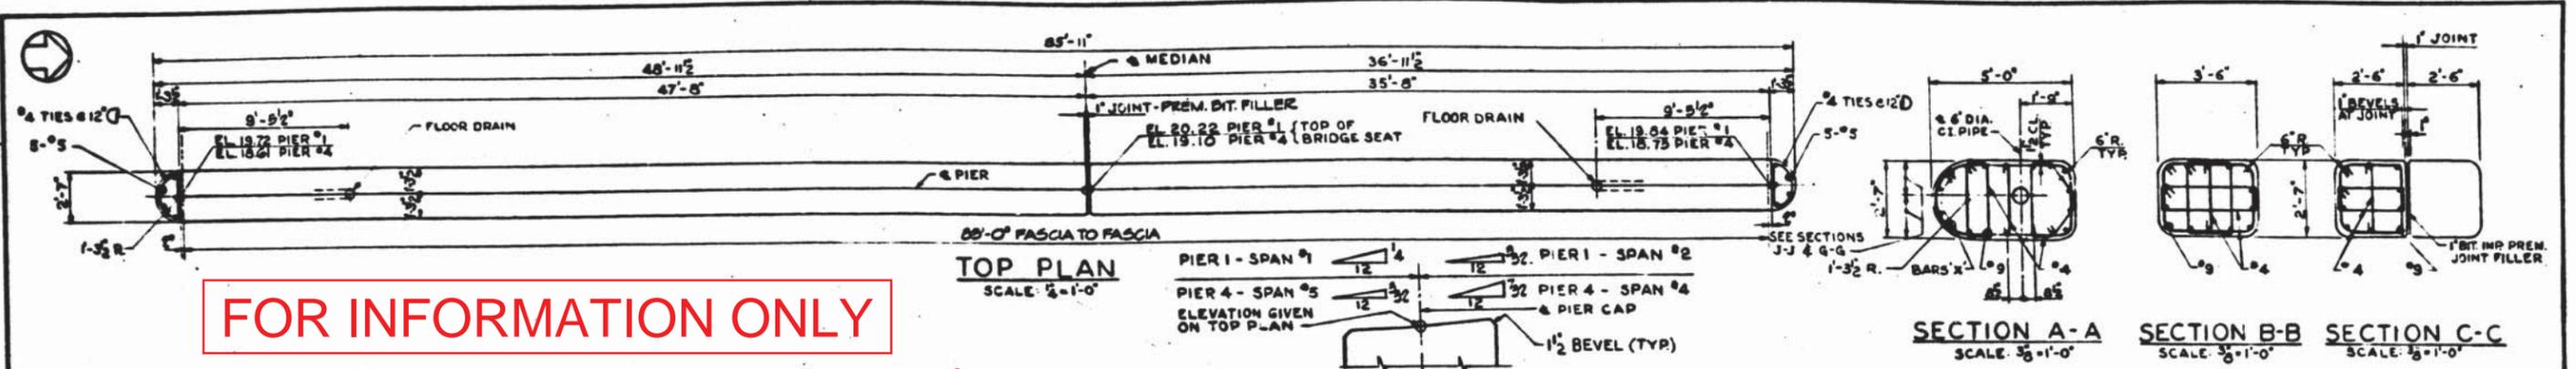

BILL OF MATERIAL

ITEM	UNIT	PIER #1	PIER #4
CLASS 'X' CONCRETE	CU YDS	144.9	142.2
REINFORCEMENT BARS	LBS	22,200	21,600
CAST IRON PIPE 6" DIA. CLASS 150	LN. FT	43	44

KEY PLAN

CONTRACT NO. 60J15
SHEET NO. 116 OF 137

NOTES:
FOR ELECTRICAL DETAILS SEE SHEET NO. 47 & 48

REVISIONS

DATE	BY	DESCRIPTION

DEPARTMENT OF HIGHWAYS
COOK COUNTY, ILLINOIS

PIERS NO 1 & 4
63RD STREET GRADE SEPARATION
OVER
SOUTH ROUTE EXPRESSWAY

COMPUTED S.G. PROJECT BUI-24-3155156
DRAWN J.R. SCALE AS SHOWN
CHECKED E.M.G. APPROVED [Signature]

APPROVED [Signature] DATE 1/16/69
F.A.I. COUNTY HIGHWAY SHEET NO. TOTAL SHEETS DRAWING NO.
94 066-1920-CF 7 48 S-6

DE LEUW, CATHAR & COMPANY
CONSULTING ENGINEERS