


NOTES:

- EQUIPMENT SHOWN SOLID IS PLATFORM MOUNTED AT ELEV. +6.0', EQUIPMENT DOTTED AT MEZZANINE ELEV +22.073', REFER TO DWG E-24 FOR DEMOLITION OF EQUIPMENT AT MEZZ LEVEL.
- 2. SHADED ZONE IS AREA TAKEN BY 5 CONDUIT TIERS UNDER MEZZ FLOOR. REFER TO DWG E-21.
- 3. REFER TO DWG E-04 AND E-05 FOR ELECTRICAL SYMBOLS.
- 4. REFER TO DWG E-65 FOR EXISTING CONDUIT AND WIRE SCHEDULE.
- 5. ALL ITEMS CROSSED BY HATCH LINES SHALL BE DEMOLISHED DURING STAGE 1 ELECTRICAL DEMOLITION ON THE EASTBOUND SIDE OF THE BRIDGE, ALL ITEMS CROSSED BY CROSSHATCH LINES SHALL BE DEMOLISHED DURING STAGE 2 ELECTRICAL DEMOLITION ON THE WESTBOUND SIDE OF THE BRIDGE.
- 6. PRIOR TO DEMOLITION (STAGE 1) THE SOUTHWEST AND THE SOUTHEAST BRIDGE LEAVES WILL BE LOCKED IN THE OPEN POSITION. PROVIDE TEMPORARY LIGHT AND POWER 24 HOURS PER DAY, 7 DAYS PER WEEK.
- 7. ALL ELECTRICAL EQUIPMENT WHICH ARE NO LONGER REQUIRED TO FUNCTION SHALL BE DE-ENERGIZED AND DISCONNECTED AT THE SOURCE OF THE POWER SUPPLY AND SHALL BE REMOVED AND COORDINATED WITH THE AUTHORITY.
- 8. ALL ELECTRICAL WORK IN ADJOINING AREAS WHICH ARE REQUIRED TO FUNCTION BUT ARE AFFECTED BY DEMOLITION WORK SHALL BE RECONNECTED AND RESTORED TO THEIR PRESENT FUNCTIONS AS PART OF THE ELECTRICAL SYSTEMS.
- 9. AT ANY TIME THE CONTRACTOR SHALL NOT PERFORM ANY DEMOLITION WORK, RELOCATION, REPAIR OR REROUTING OF EXISTING CABLES, CONDUITS, JUNCTION BOXES OR ANY EQUIPMENT WITHOUT OBTAINING FULL CLEARANCE OF ANY ASBESTOS, AND/OR LEAD CONTAINING MATERIALS. CONTRACTOR SHALL NOTIFY IDOT FOR EXISTENCE OF ASBESTOS AFFECTED BY THE DEMOLITION WORK.
- 10. ALL ELECTRICAL EQUIPMENT BEING REMOVED SHALL BE DISPOSED OF AT NO ADDITIONAL COST TO THE AUTHORITY. ANY EQUIPMENT REQUIRED TO BE TURNED OVER TO THE AUTHORITY SHALL BE DELIVERED, THE EXACT LOCATION AND TIME OF DELIVERY WILL BE DETERMINED BY THE ENGINEER TWO WEEKS PRIOR TO THE EQUIPMENT BEING REMOVED.
- 11. FOLLOW THE SAME STEPS FOR STAGE 2 DEMOLITION.
- 12. REFER TO DWGS E-39 THROUGH E-45 FOR NEW POWER LAYOUTS.

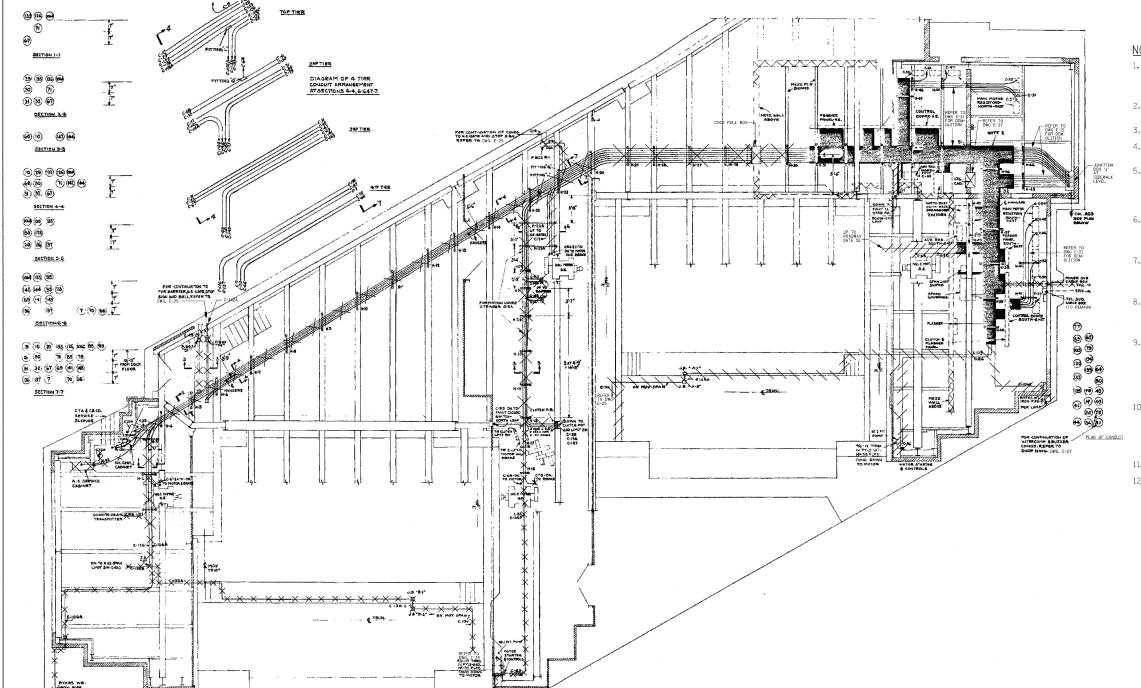

EAST SIDE DOCK LEVEL
PLAN

PB Americas, Inc. 230 WEST MONROE STREET,
SUITE 900
CHICAGO, IL. 60606

PIER LAMP

STATE OF ILLINOIS
DEPARTMENT OF TRANSPORTATION

POWER AND CONTROL CONDUITS - EAST SIDE DOCK LEVEL - SHEET 1

SCALE: AS SHOWN | SHEET NO. E-20 OF E-125 SHEETS | STA. 379+06.09 TO STA. 382+45.28

| CONTRACT NO. 60D61