
Z**∢⊕**◀

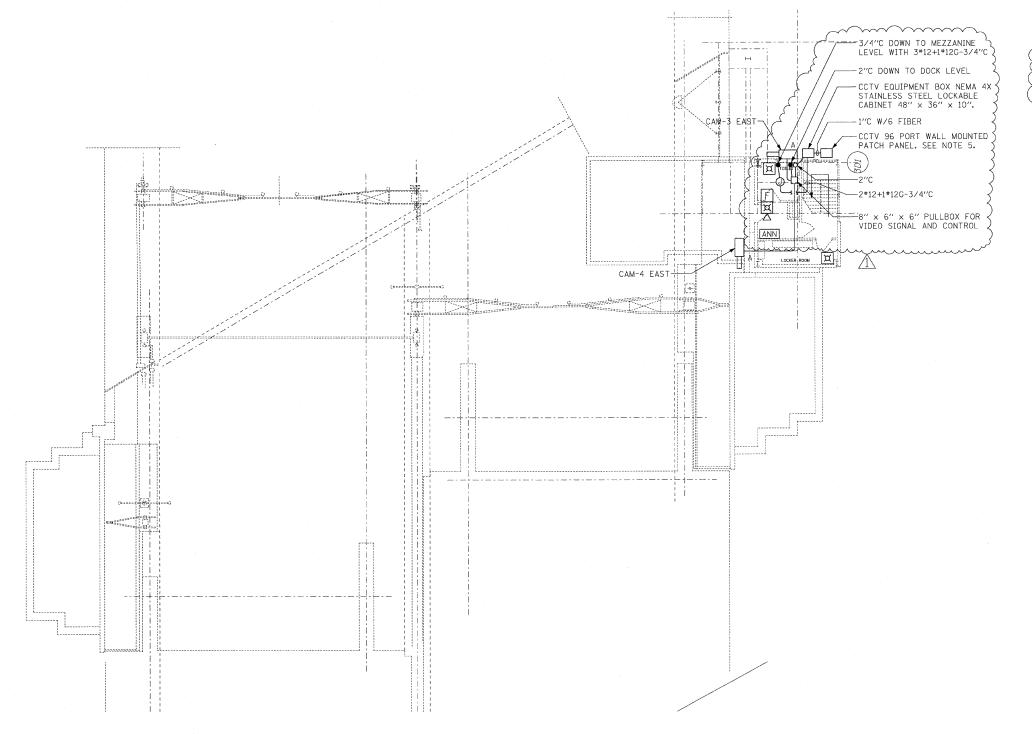

## NOTES:

- 1. FOR ELECTRICAL SYMBOLS AND ABBREVIATIONS SEE DWGS E-04, E-05 AND E-06.
- 2. FOR GENERAL NOTES SEE DWG E-02 AND E-03.
- 3. FOR FIRE ALARM RISER DIAGRAM, SEE DWG E-16.
- 4. FOR CCTV RISER DIAGRAM, SEE DWG E-17.
- 5. NEMA 4X STAINLESS STEEL LOCKABLE CABINET

  48" × 36" × 10". SIZE TO BE DETERMINED BY DEPARTMENT
  TIE-IN REQUIREMENTS.
- 6. FOR CCTV 96 PORT WALL MOUNTED PATCH PANEL ELEVATIONS SEE DWG E-54.

ADDENDUM - JULY 14, 2009

PB Americas, Inc. 230 WEST MONROE STREET, SUITE 900 CHICAGO, IL. 60606

 USER NAME = sharma	DESIGNED	~	R. GODULIAS	REVISED -
FILE NAME = D160d61-sht-elc-49.dgn	DRAWN	-	S. SHARMA	REVISED -
PLOT SCALE = NONE	CHECKED	-	M. INTATANO	REVISED -
PLOT DATE = 5/7/2009	DATE	-	MAY 8, 2009	REVISED -

AUXILIARY SYSTEMS PLAN
1/8" = 1'-0"

STATE OF ILLINOIS
DEPARTMENT OF TRANSPORTATION

	AUXILIARY SYSTEMS PLAN EAST SIDE SIDEWALK LEVEL	
SCALE: AS SHOWN	SHEET NO. E-49 OF E-125 SHEETS   STA. 379+06.09 TO STA. 382+45.28	