



TYPICAL SPLICE DETAIL

N.T.S.

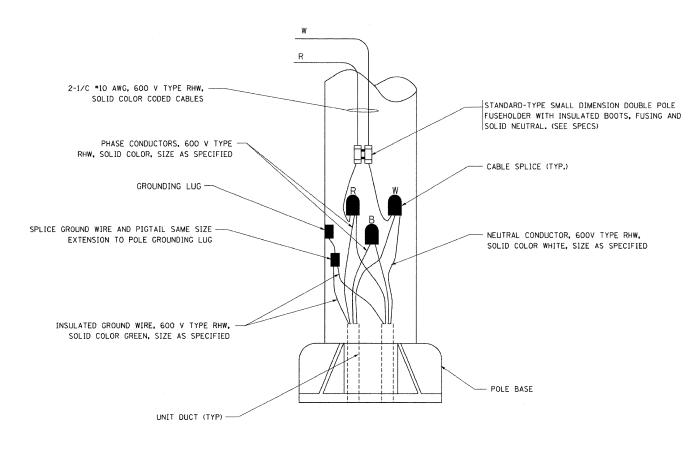

POLE WIRING DETAIL

N.T.S.

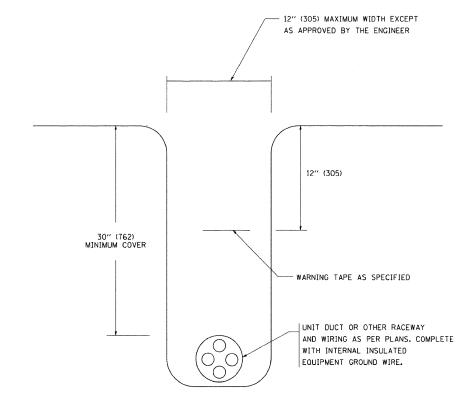

TYPICAL WIRING IN TRENCH DETAIL

N.T.S.

LOVO, IVC	USER NAME = \$USER\$	DESIGNED -	MJY & ST	REVISED -
		DRAWN -	ST	REVISED -
CONSULTING ENGINEERS 1560 WALL ST. SUITE 222	PLOT SCALE = \$SCALE\$	CHECKED -	WHE	REVISED -
NAPERVILLE, ILLINOIS 60563 PH: (630) 577-9100	PLOT DATE = \$DATE\$	DATE -	07/08/2009	REVISED -

STATE OF ILLINOIS
DEPARTMENT OF TRANSPORTATION

MISC. ELECTRICAL DETAILS, SHEET A				
I–80	RAMP (EASTBOUND TO	NORTH BOUND 1-57)		
SCALE: N.T.S.	SHEET NO. 4 OF 4 SHEETS	STA. TO STA.		

L4C