



F.A.L. RTE.	SECTION	COUNTY	TOTAL SHEET
2552	00-00114-00-PV	DUPAGE	563
STA.	TO STA.		236
FED. ROAD DIST. NO.	ILLINOIS FED. AID PROJECT		

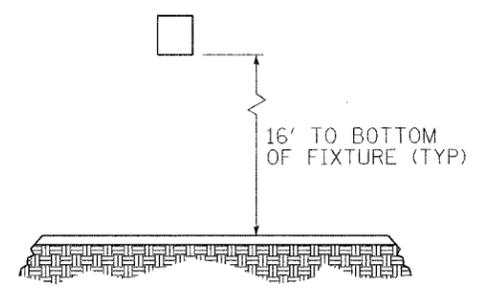

DETAIL 1

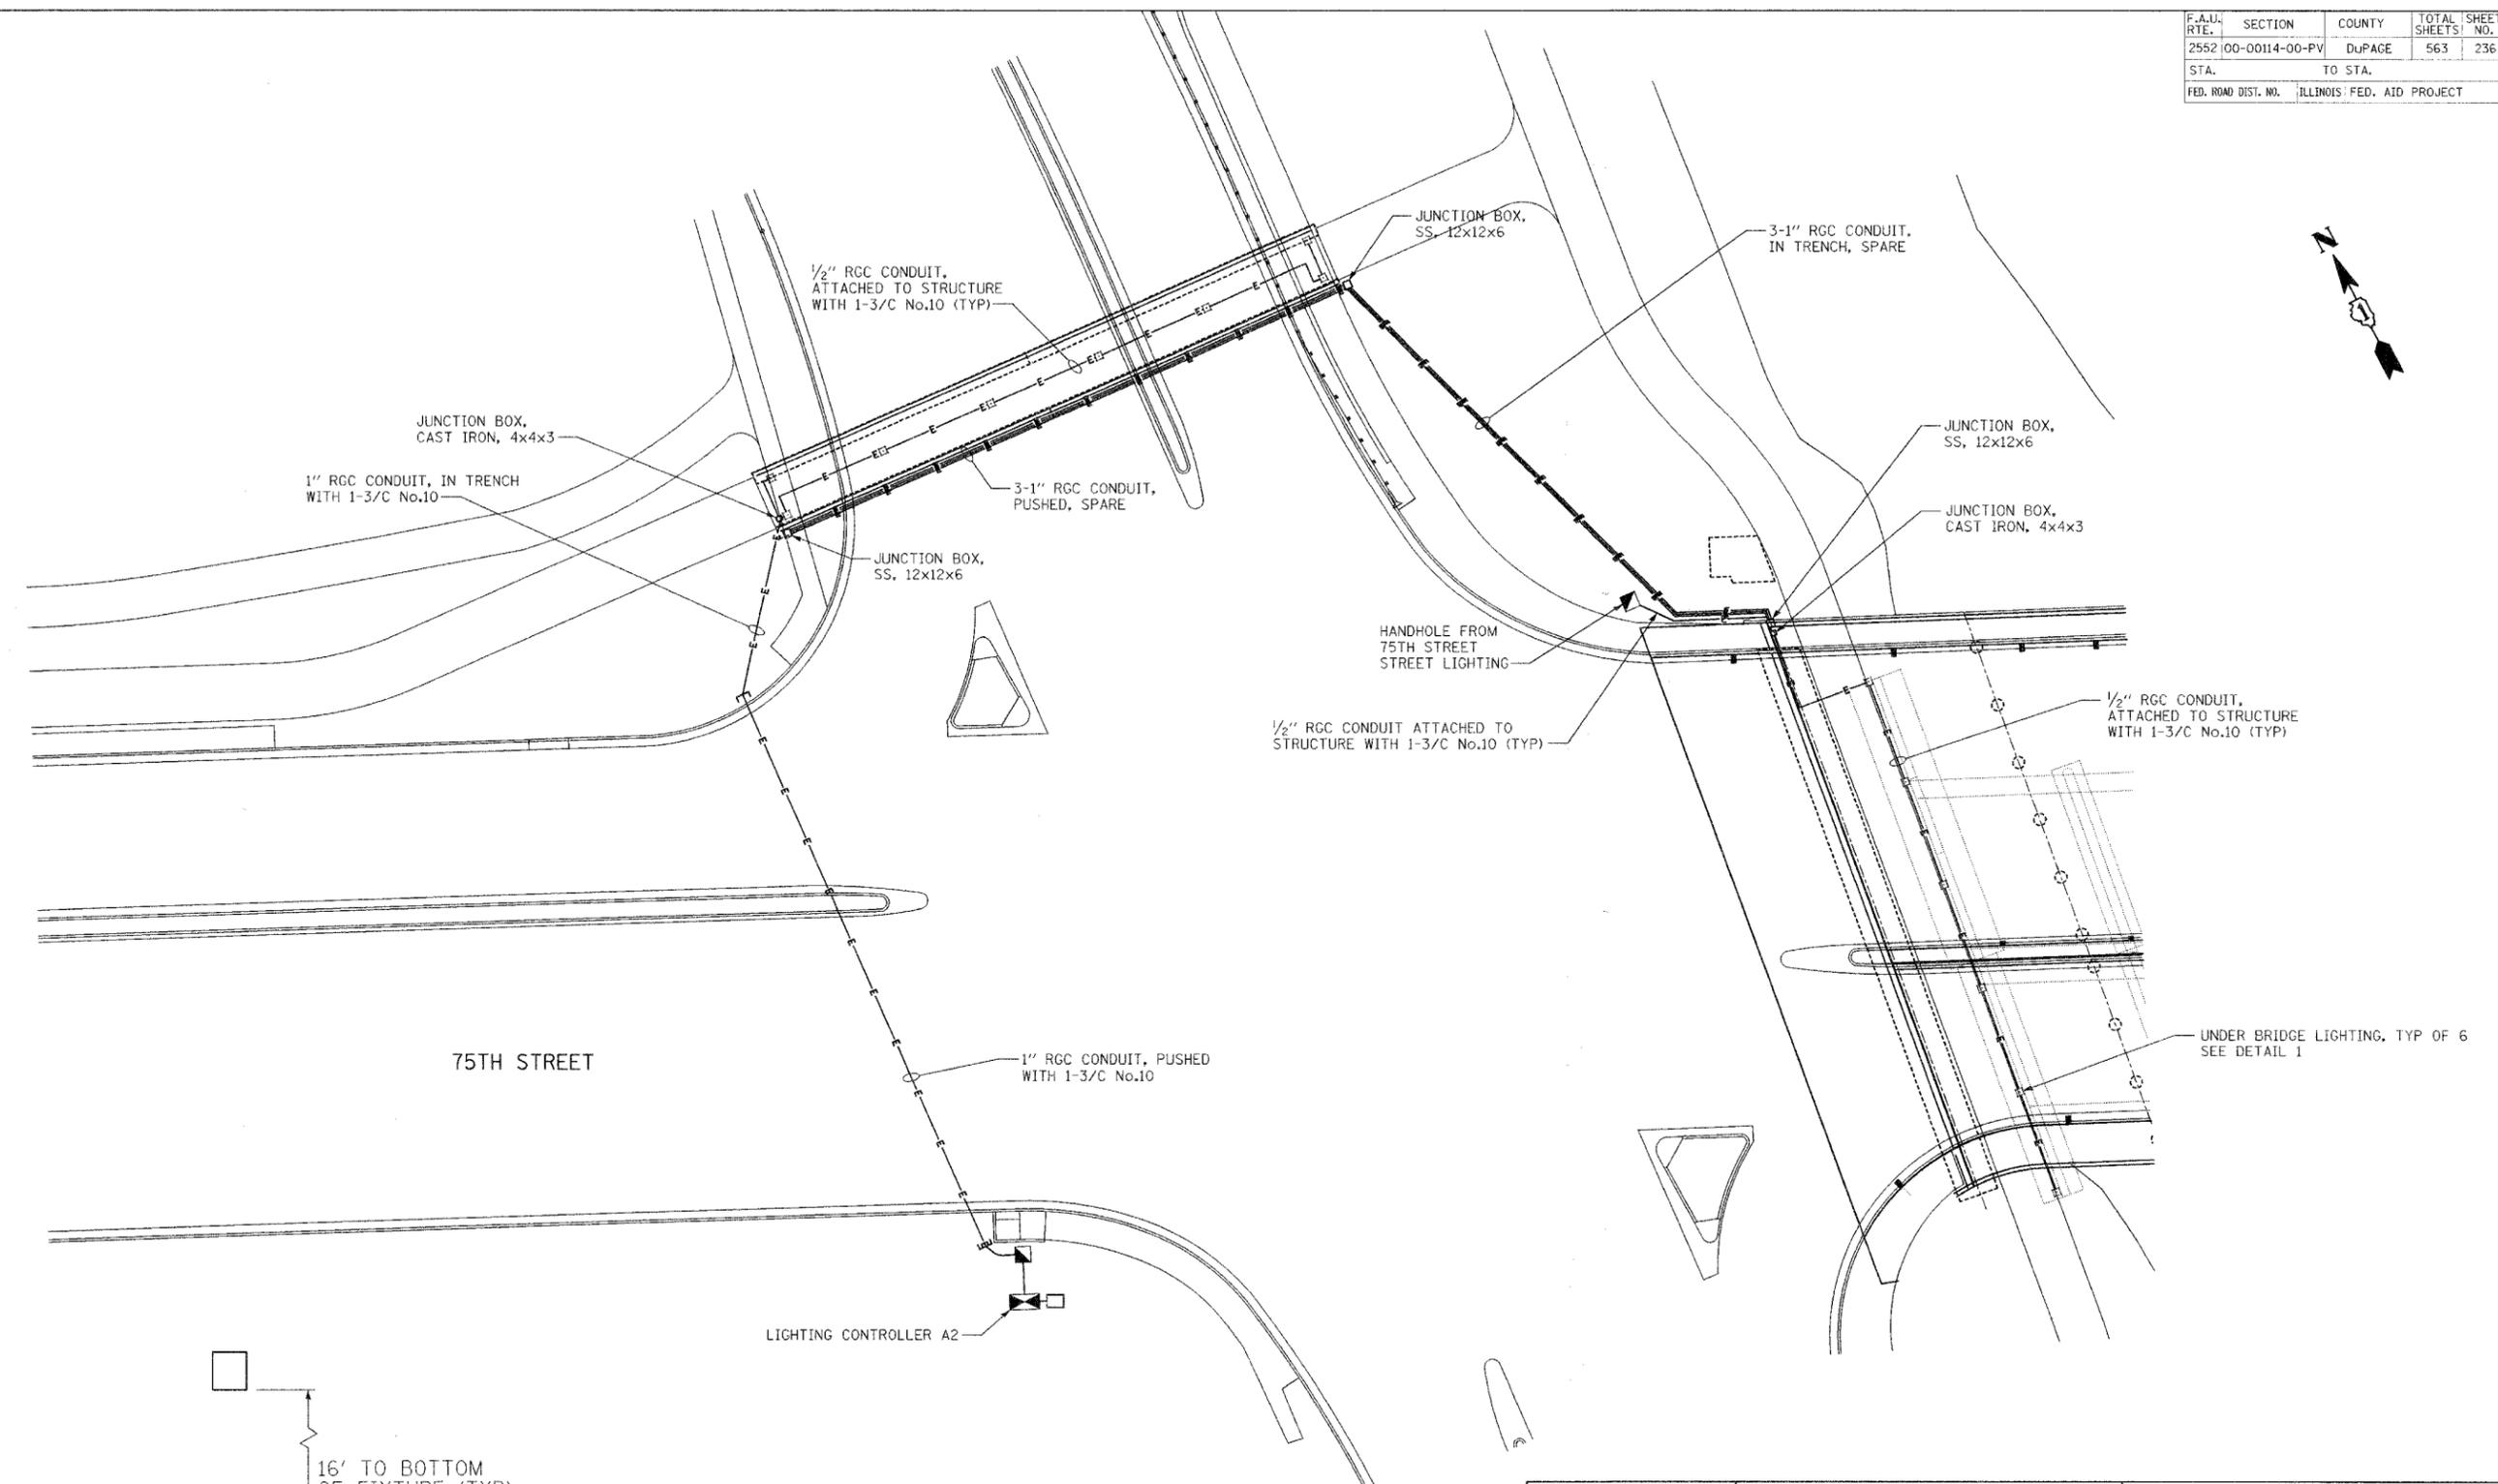

REVISIONS	
NAME	DATE

INTERSECTION IMPROVEMENT
 WASHINGTON STREET - 75th STREET
 PROPOSED ELECTRICAL PLAN
 PEDESTRIAN WALKWAY
 SHEET 1 OF 1

CONSULTANT
TYLIN INTERNATIONAL

City of  **Naperville**

DRAWN: JRH
 CHECKED: FI
 APPROVED: DEM
 DATE: 04/11/08
 SCALE: 1" = 0'-0"
 JOB NO.: P-91-494-00

SHEET NO.
 PROJECT NO.: CMM-7003 (983)