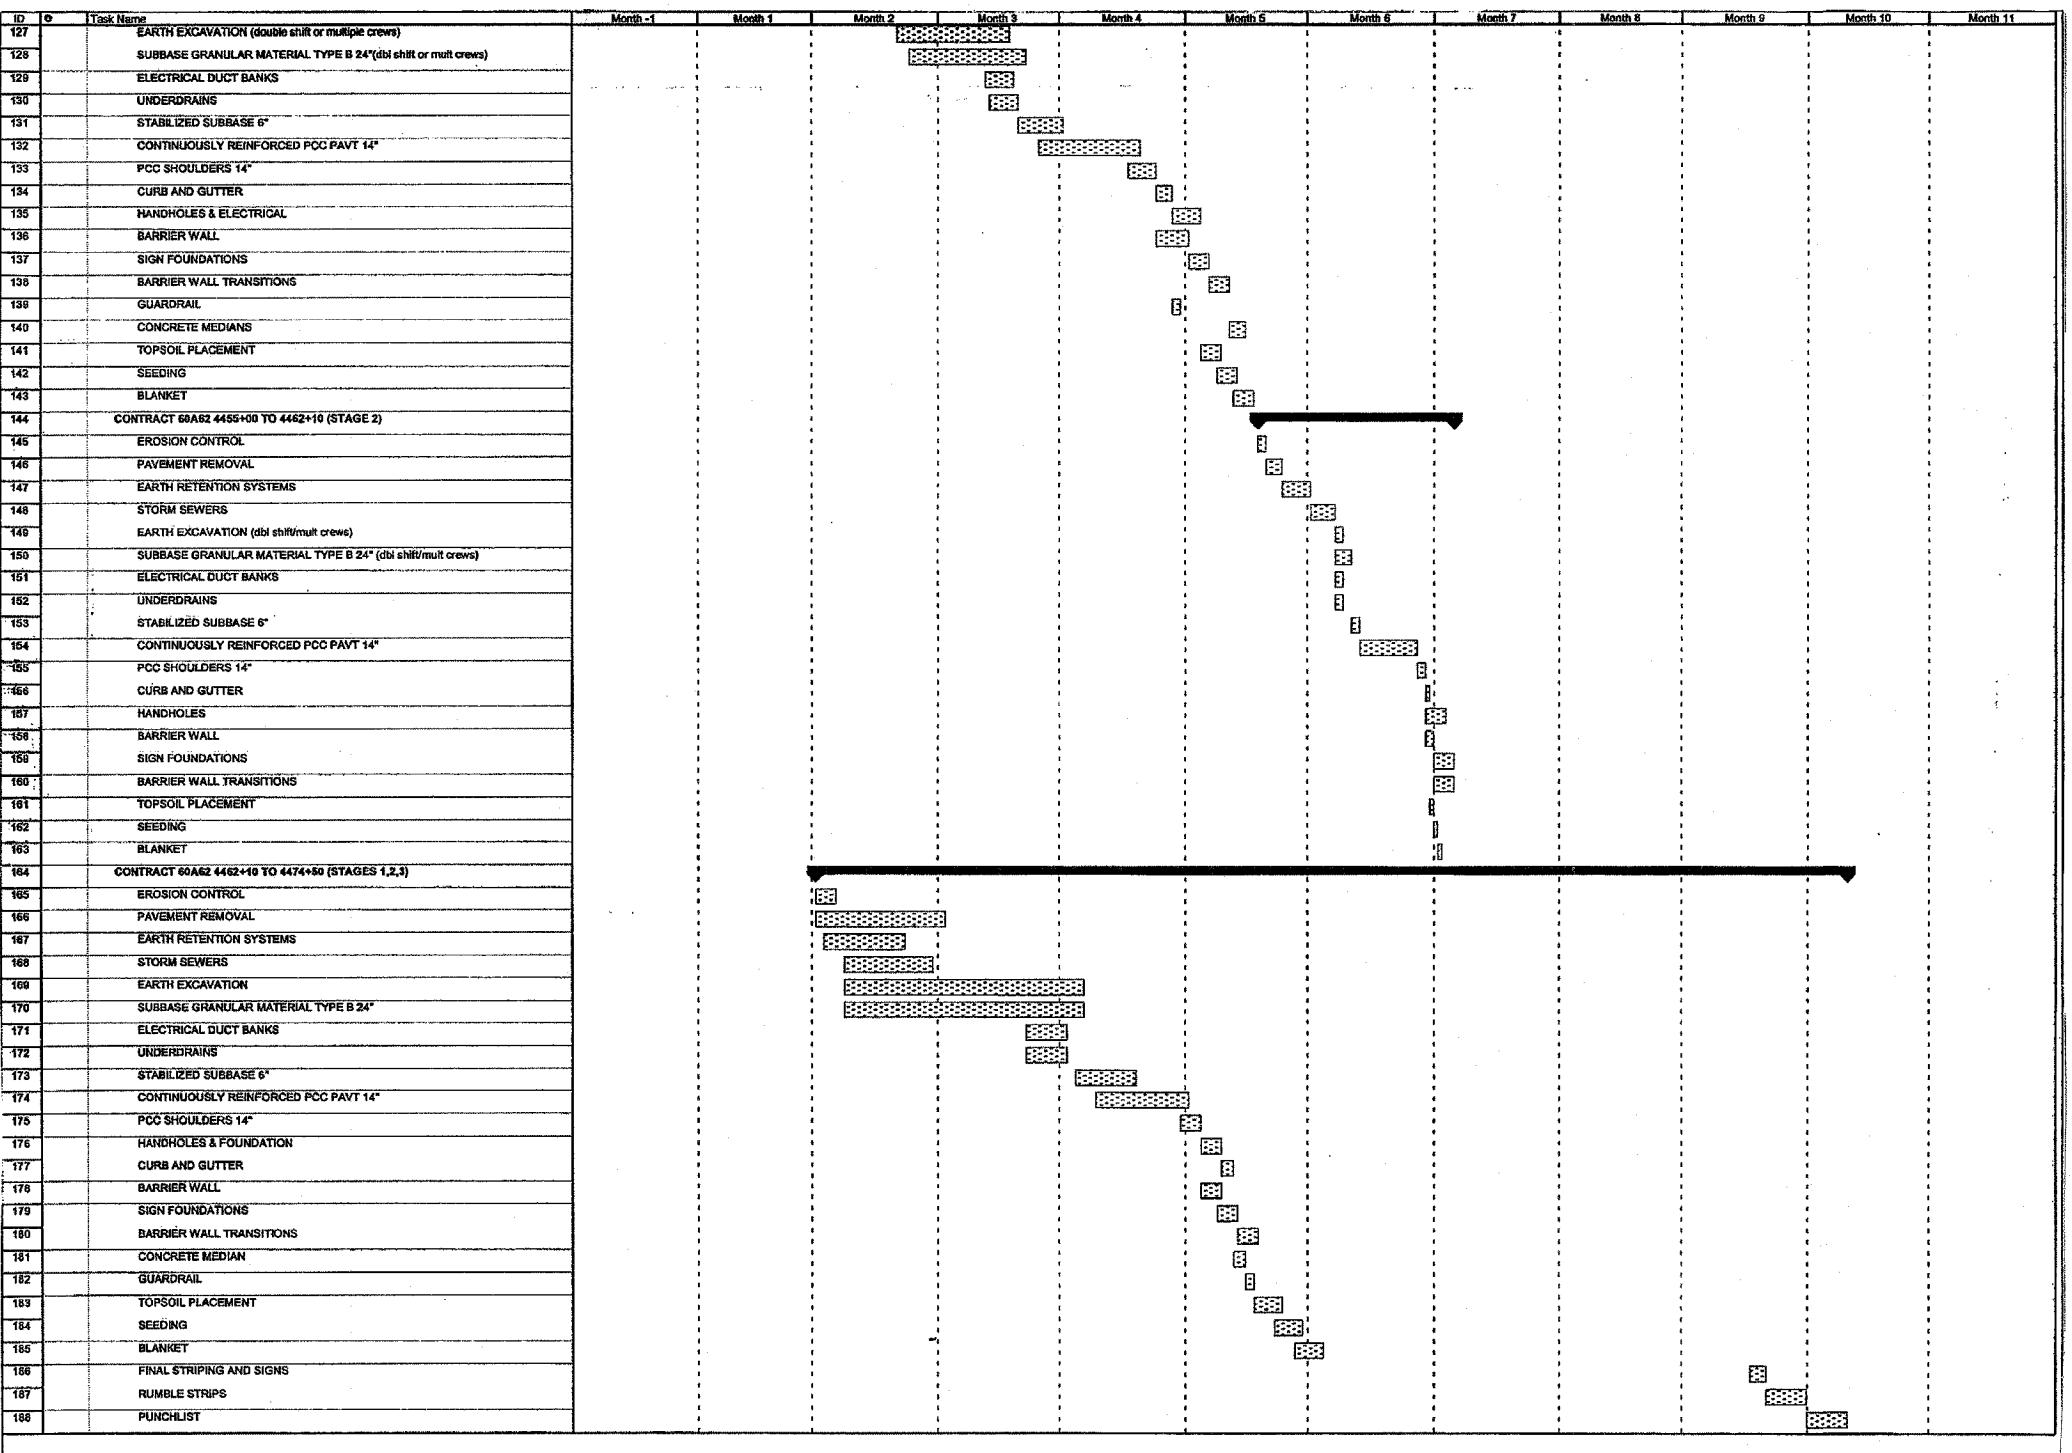


F.A.I. RTE.	SECTION	COUNTY	TOTAL SHEETS	SHEET NO.
90/94	*	COOK	565	6
STA.	TO STA.			
FED. ROAD DIST. NO. I	ILLINOIS	FED. AID PROJECT		
62301	(2021-922 PT2 ETC 2324.6-1P)	R-10		

GSI80032057

PPD/04/08/GW/NG-001.s /G &amp; GSI/achr Resched/Resched

Project: DAN RYAN 16 & 18A  
Date: Fri 6/2/06Task  
SpRProgress  
\*\*\*\*\*Summary  
-----Milestone  
◆Rolled Up Spill  
-----Rolled Up Progress  
-----Project Summary  
-----Deadline  
↓Rolled Up Task  
-----Rolled Up Milestone  
◆External Tasks  
-----External Milestone  
◆

Page 3

CS-3

10/20/30 AW

CTE | AECOM

REVISIONS		ILLINOIS DEPARTMENT OF TRANSPORTATION
NAME	DATE	F.A.I. 90/94 (DAN RYAN EXPRESSWAY)
GARFIELD BLVD TO 31ST STREET (NB LOCAL LANES)		
SUGGESTED SEQUENCE OF OPERATION		
SCALE: NONE		DRAWN BY: NJH
DATE: June 9, 2006		CHECKED BY: RMG