




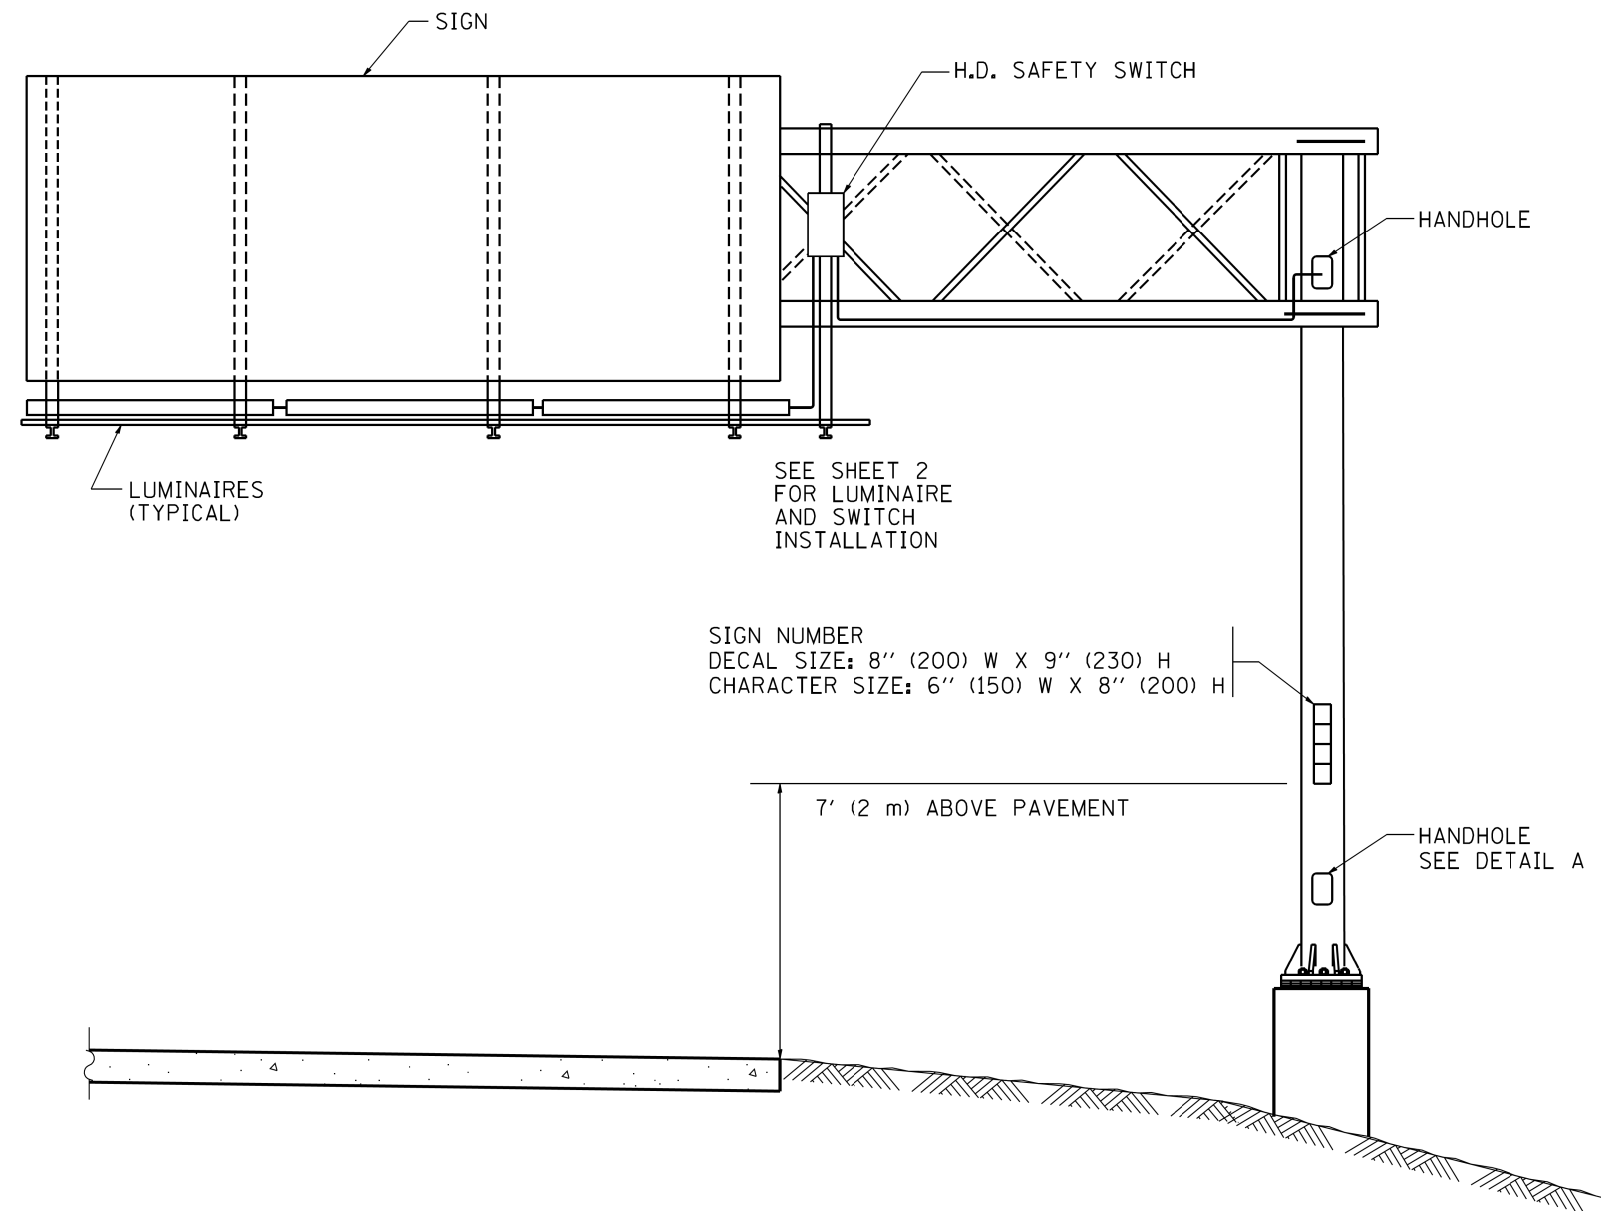


- NOTES:
1. ALL DIMENSIONS ARE IN INCHES (MILLIMETERS) UNLESS OTHERWISE SHOWN
  2. ALL CONDUIT ATTACHED TO STRUCTURE SHALL BE GALVANIZED RIGID METALIC CONDUIT, PVC COATED (GRMC, PVC)
  3. THE USE OF LIQUID TIGHT METAL CONDUIT (TYPE LFMC) SHALL BE LIMITED TO LOCATIONS WHERE MOVEMENT IS ANTICIPATED AND SHALL NOT EXCEED 5' (1.5M) IN LENGTH
  4. ALL WORK INDICATED SHALL BE INCLUDED IN THE PAY ITEM FOR ELECTRIC CONNECTION TO SIGN STRUCTURE
  5. THE SAFETY SWITCH SHALL BE LOCATED ON THE SIDE OF THE SIGN STRUCTURE WHICH IS CLOSEST TO THE SHOULDER, OR EDGE OF PAVEMENT.

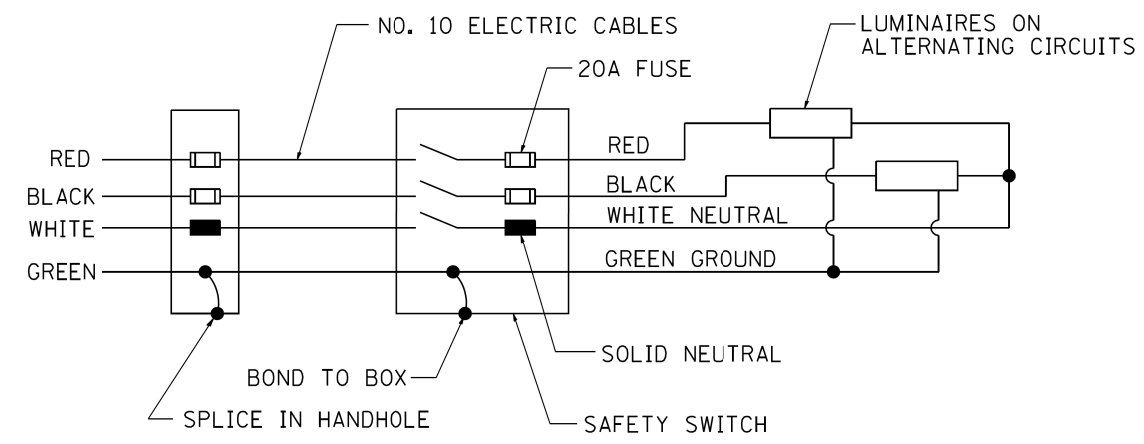


WIRING DIAGRAM

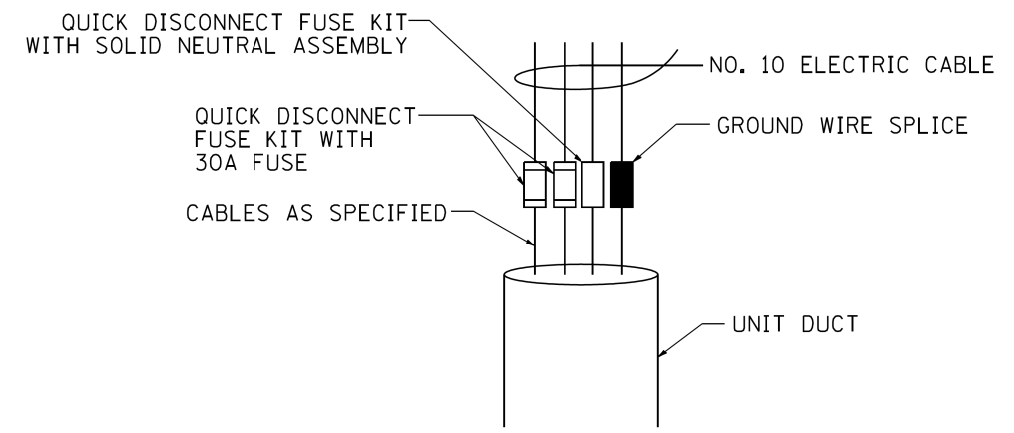



DETAIL A

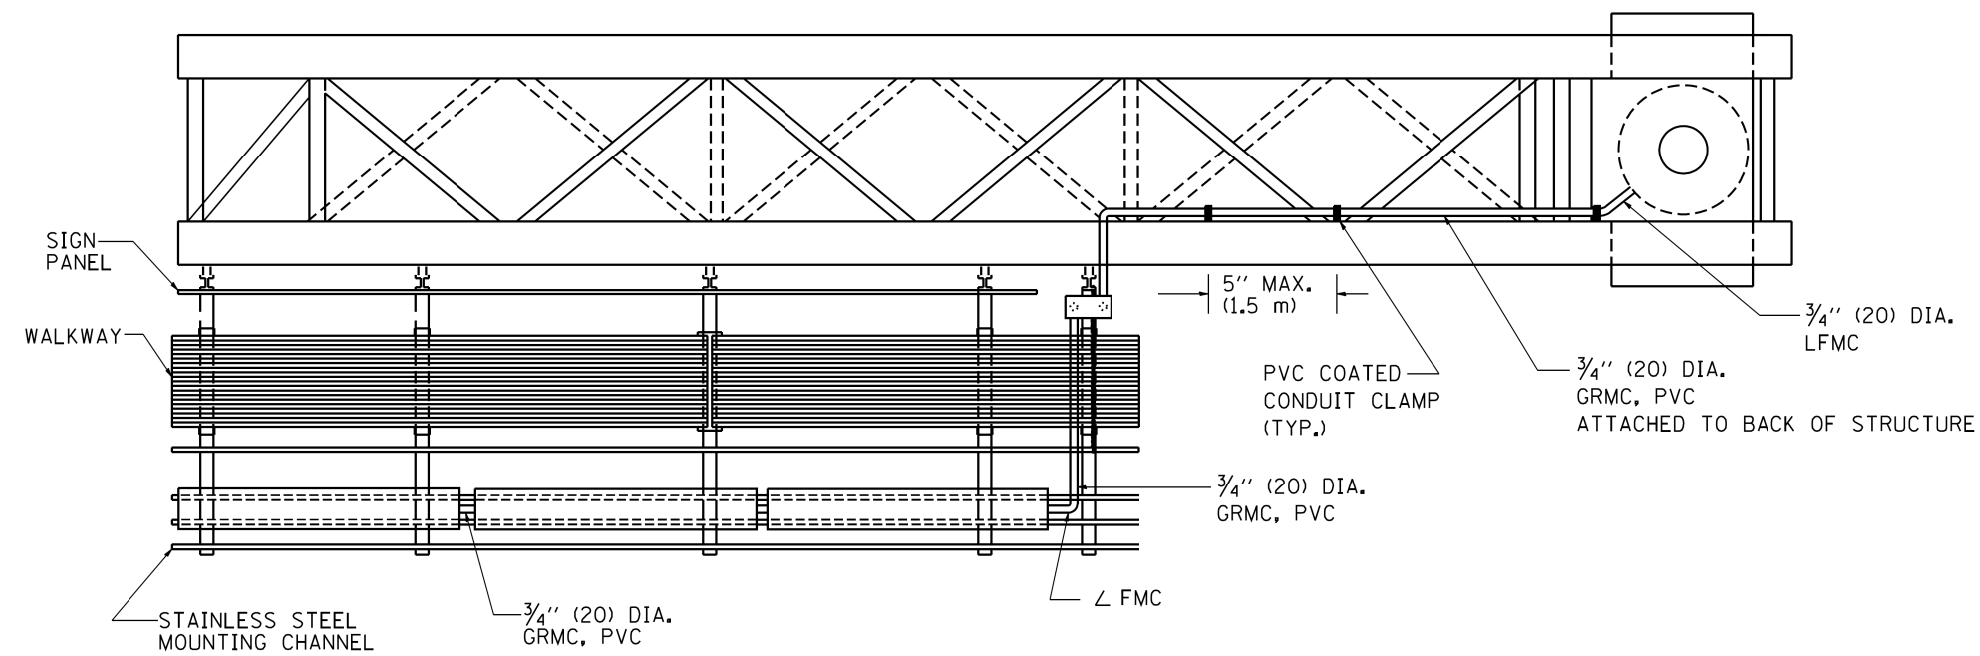


TOP VIEW

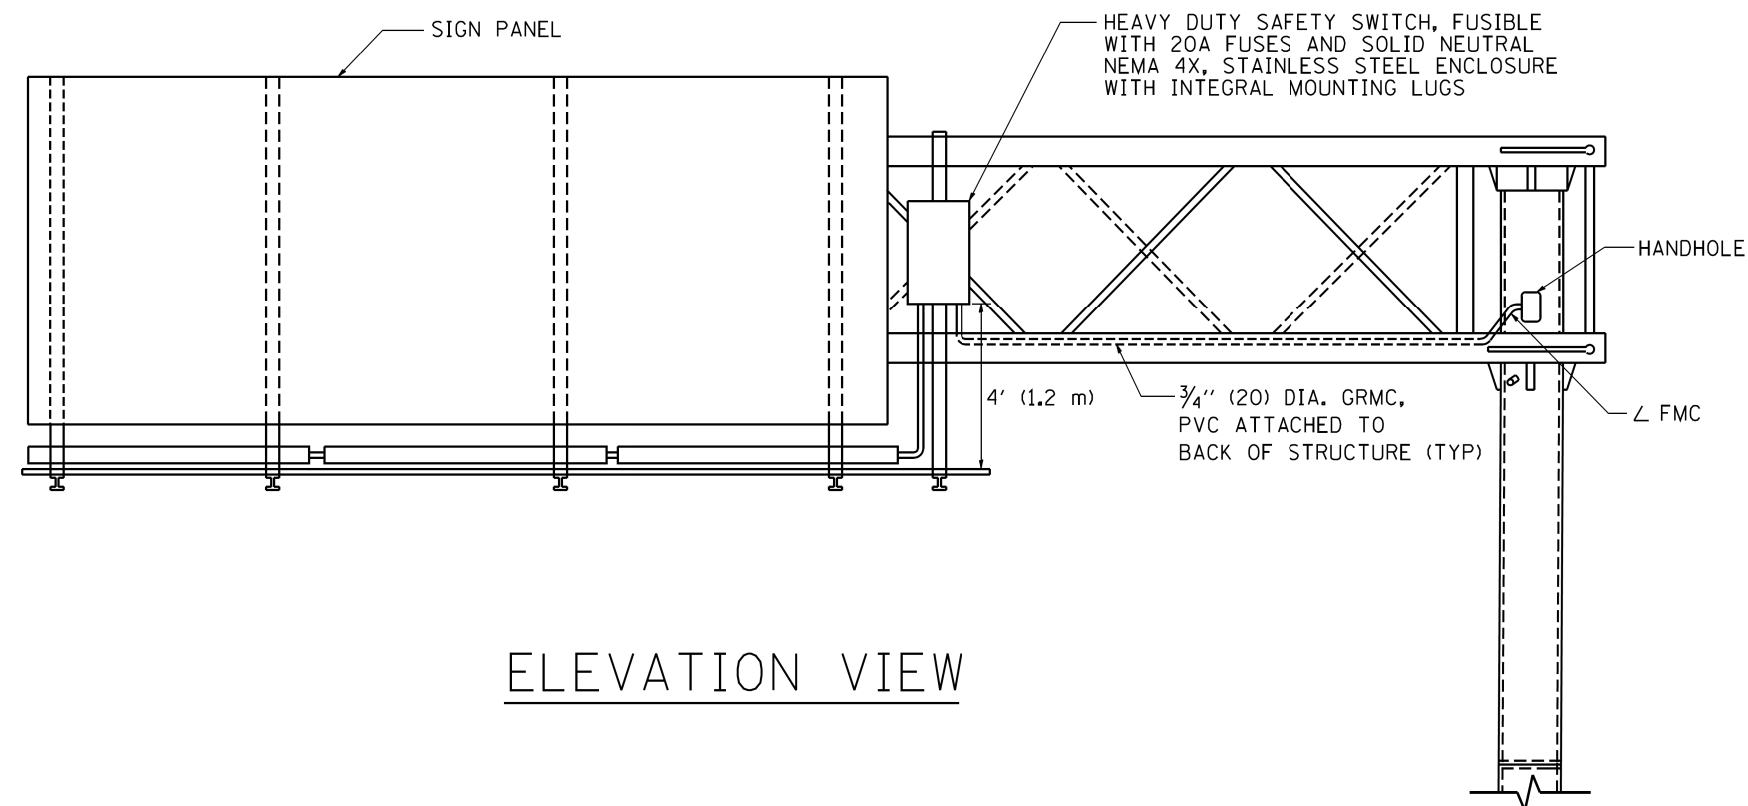

ELEVATION VIEW

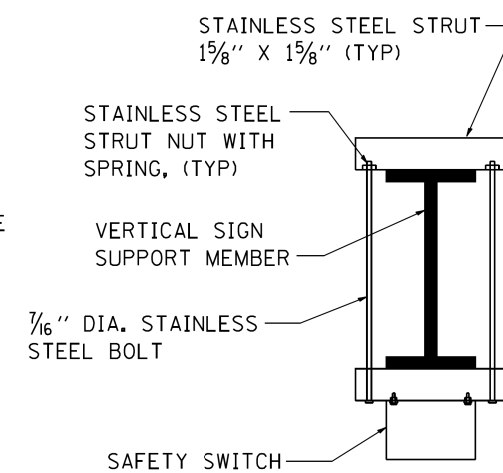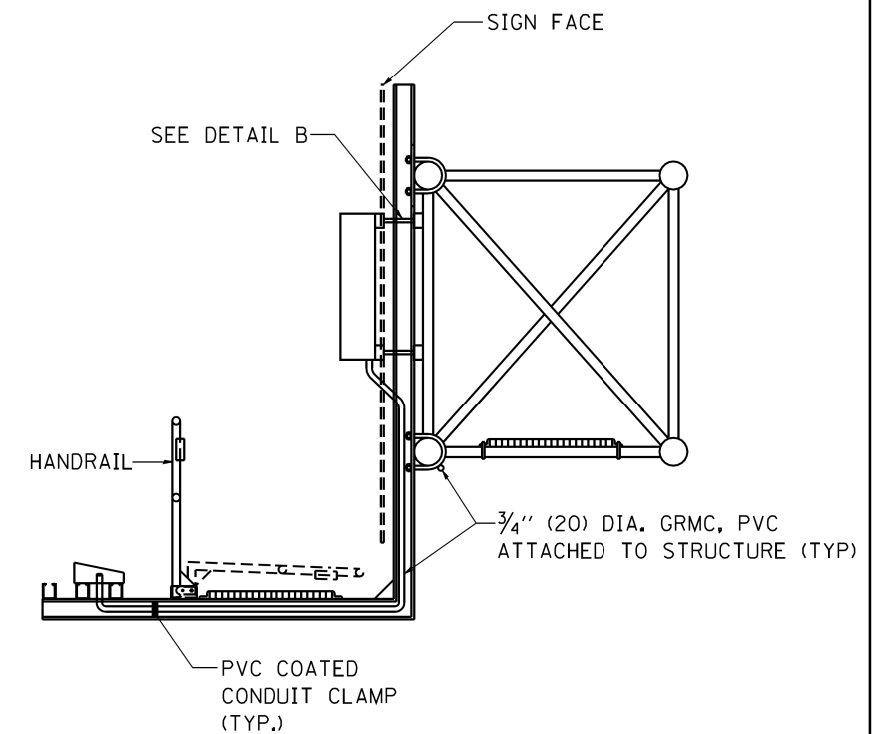

TOP VIEW

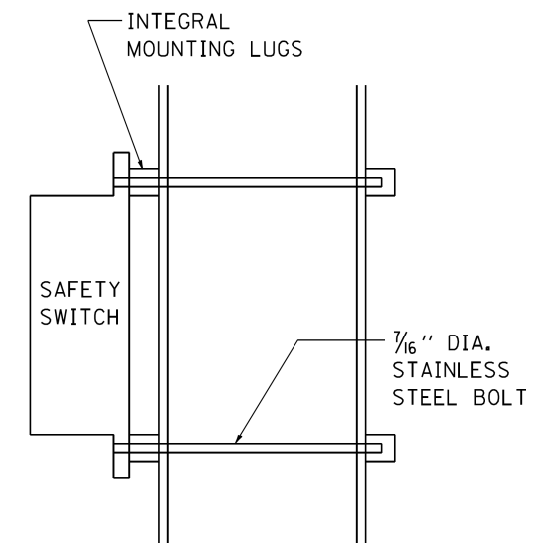

SIDE VIEW





DETAIL B

|                                           |                             |            |                    |                                                   |                                                          |  |  |                                                 |           |        |                 |              |
|-------------------------------------------|-----------------------------|------------|--------------------|---------------------------------------------------|----------------------------------------------------------|--|--|-------------------------------------------------|-----------|--------|-----------------|--------------|
| FILE NAME =<br>W:\diststd\22x34\be601.dgn | USER NAME = geglianobt      | DESIGNED - | REVISED - 08-19-04 | STATE OF ILLINOIS<br>DEPARTMENT OF TRANSPORTATION | ELECTRIC CONNECTION TO SIGN STRUCTURE<br>CANTILEVER TYPE |  |  | F.A.I. -<br>RTE.                                | SECTION   | COUNTY | TOTAL<br>SHEETS | SHEET<br>NO. |
|                                           | PLOT SCALE = 50.0000' / IN. | DRAWN -    | REVISED -          |                                                   |                                                          |  |  | 90/94                                           | 2012-0521 | COOK   | 165             | 102          |
|                                           | PLOT DATE = 1/4/2008        | CHECKED -  | REVISED -          |                                                   | SCALE: NONE SHEET NO. 2 OF 2 SHEETS STA. TO STA.         |  |  | BE-601 CONTRACT NO. 60T93                       |           |        |                 |              |
|                                           |                             | DATE -     | REVISED -          |                                                   |                                                          |  |  | FED. ROAD DIST. NO. 1 ILLINOIS FED. AID PROJECT |           |        |                 |              |








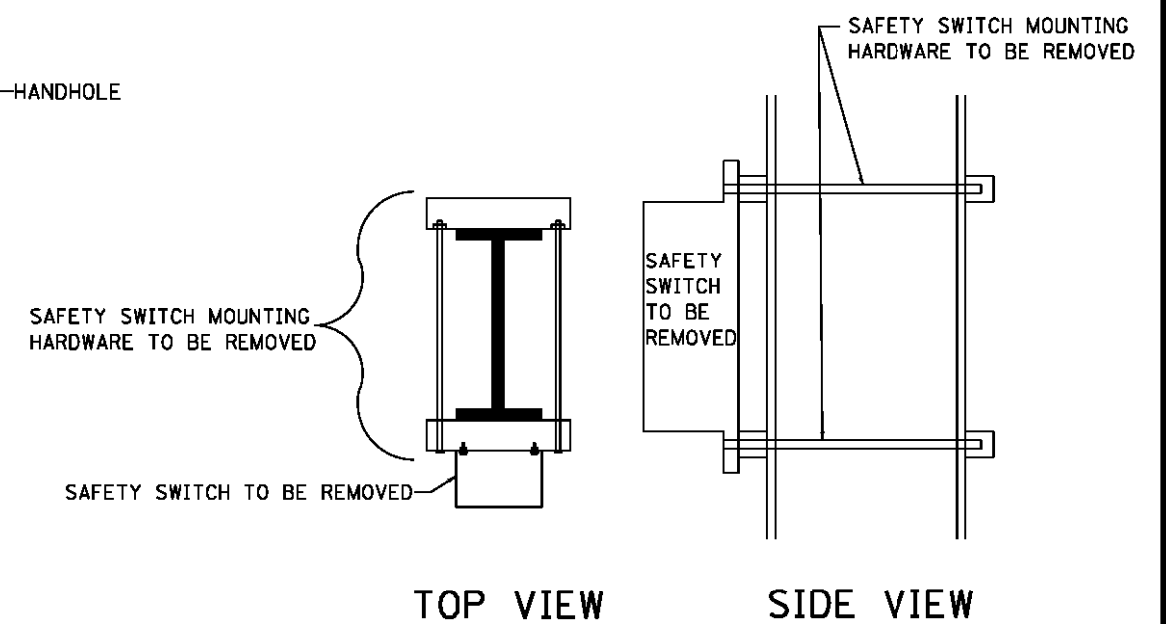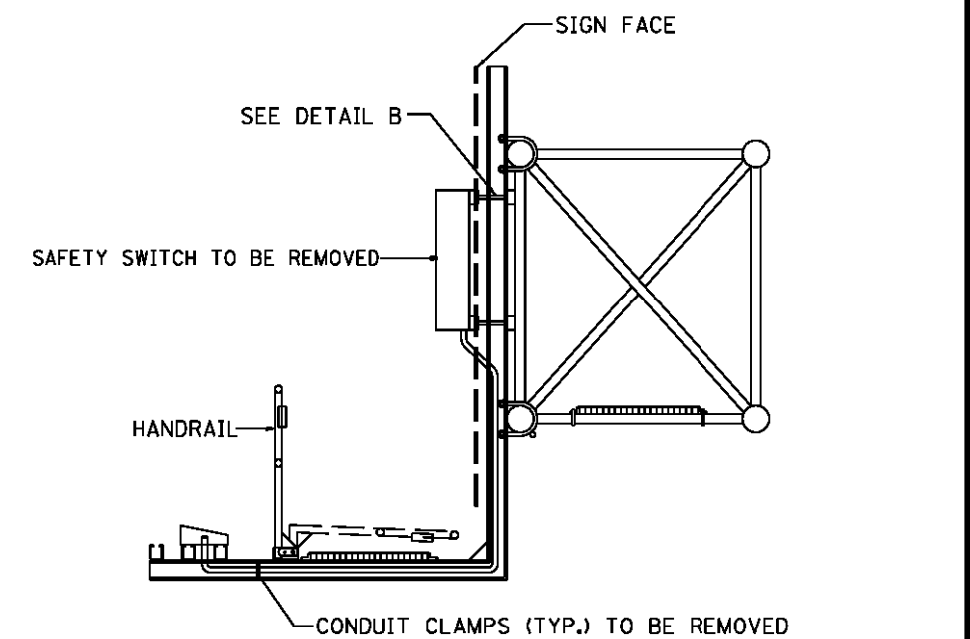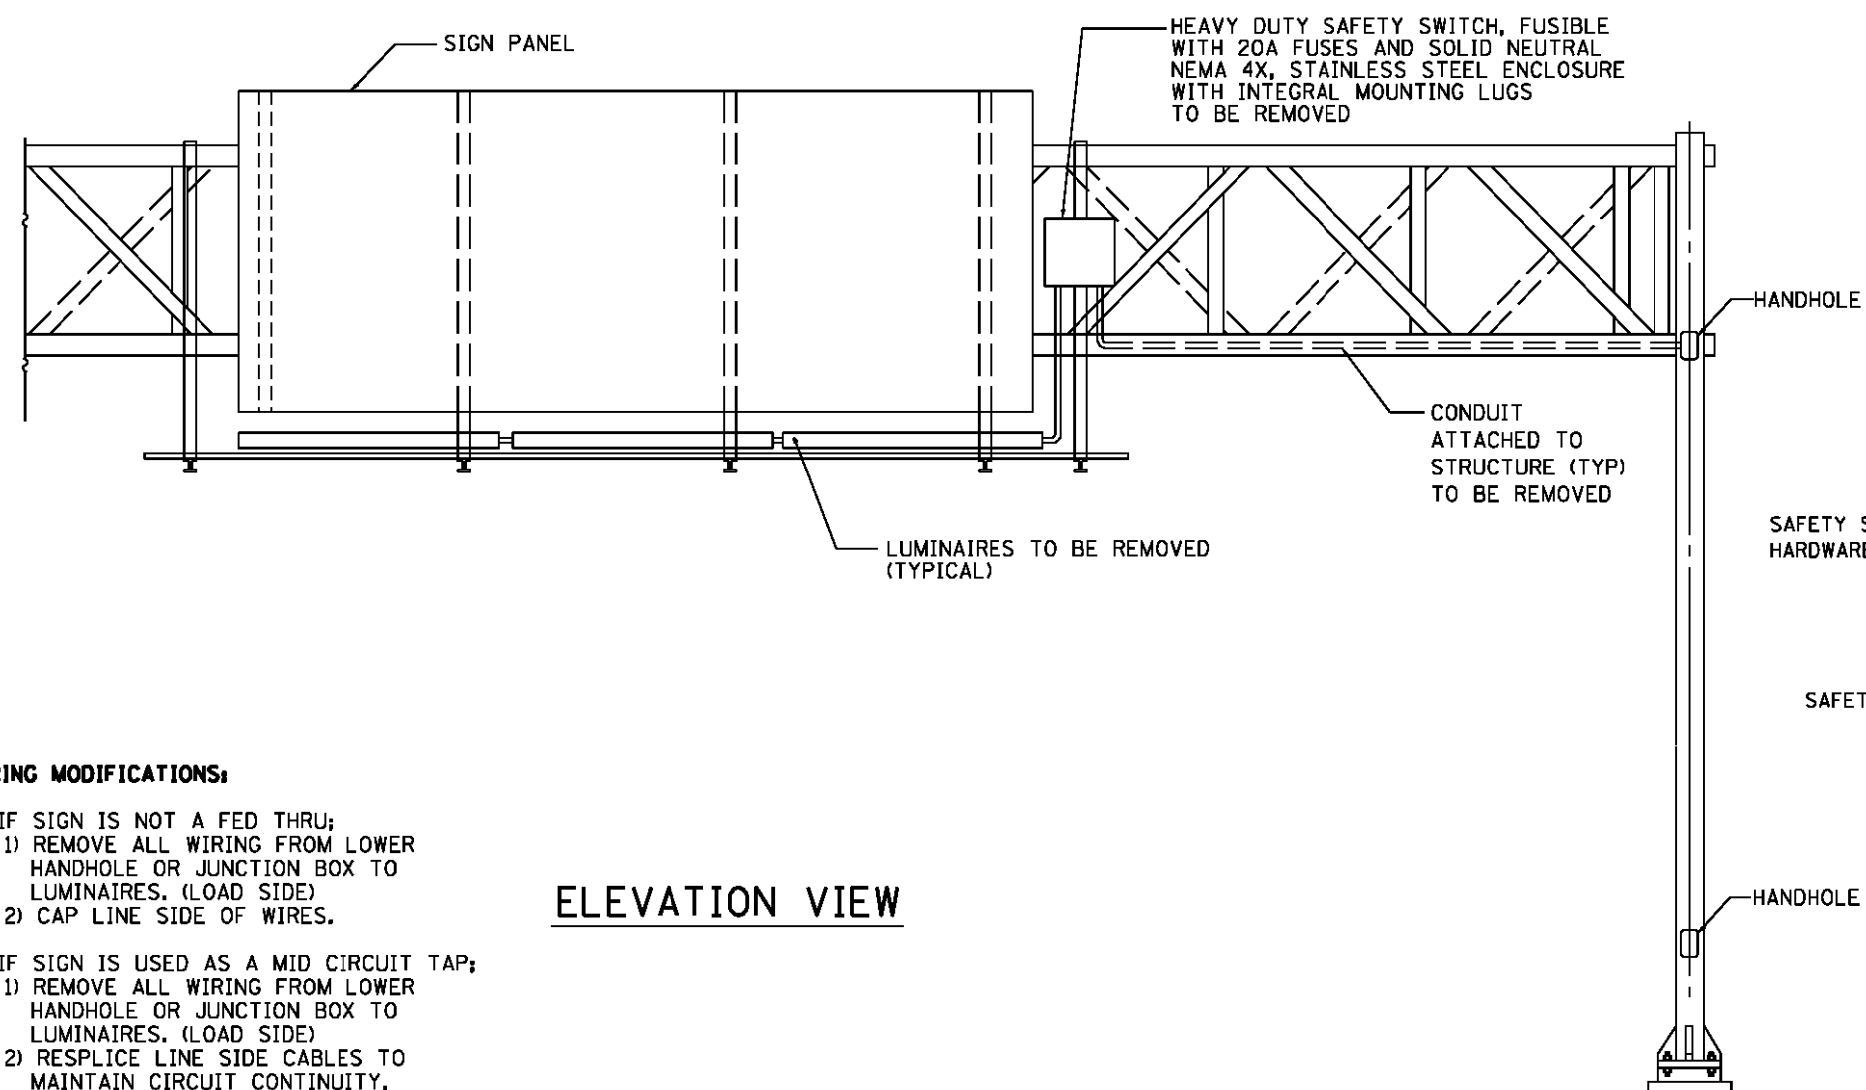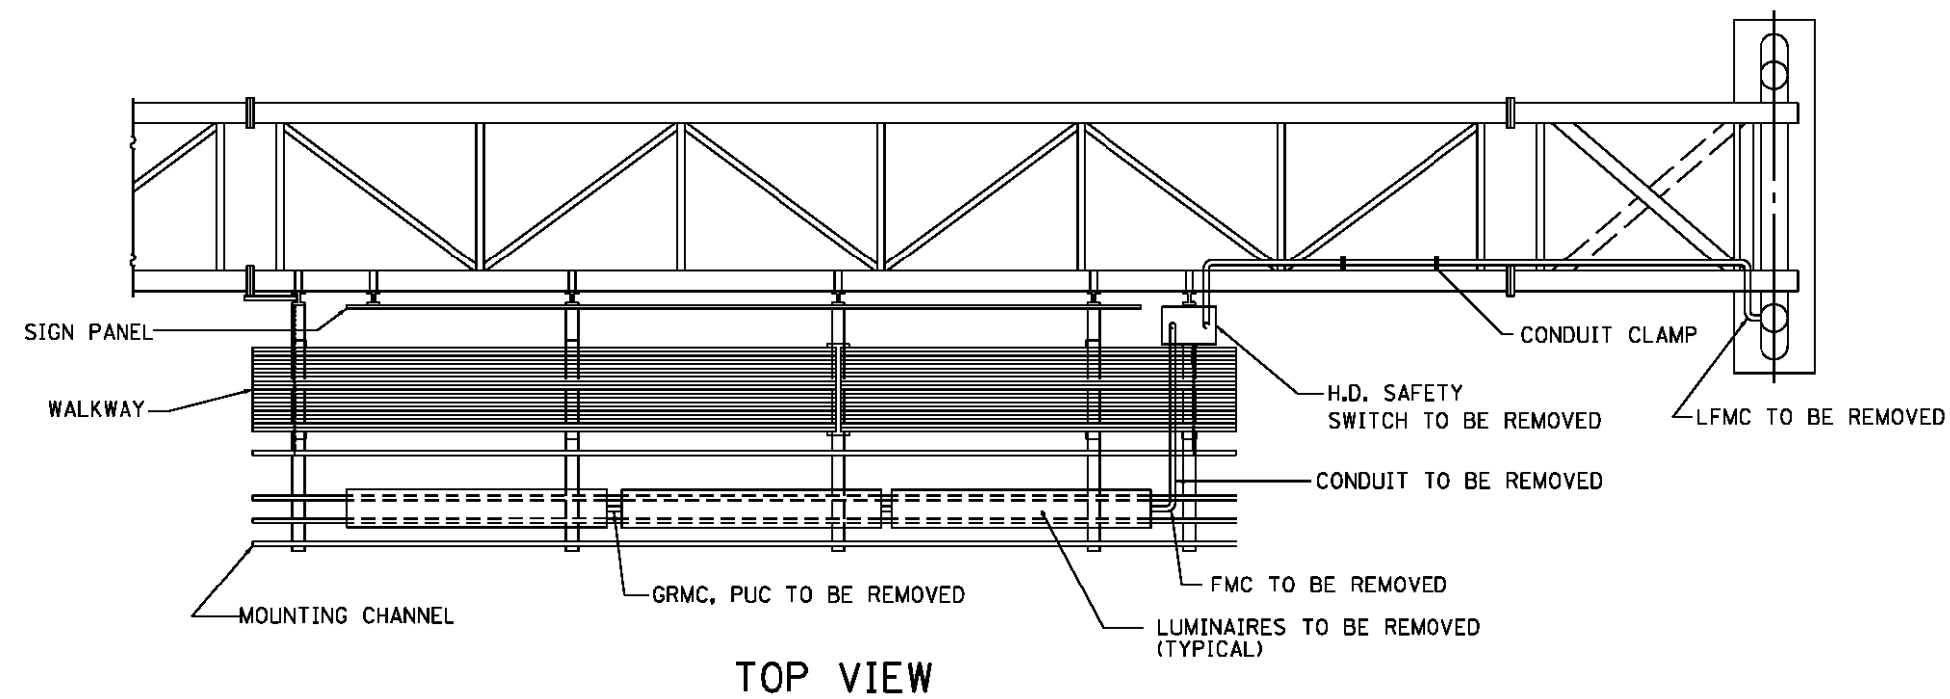


**WIRING MODIFICATIONS:**

- A) IF SIGN IS NOT A FED THRU;
  - 1) REMOVE ALL WIRING FROM LOWER HANDHOLE OR JUNCTION BOX TO LUMINAIRES. (LOAD SIDE)
  - 2) CAP LINE SIDE OF WIRES.
  
- B) IF SIGN IS USED AS A MID CIRCUIT TAP;
  - 1) REMOVE ALL WIRING FROM LOWER HANDHOLE OR JUNCTION BOX TO LUMINAIRES. (LOAD SIDE)
  - 2) RESPLICE LINE SIDE CABLES TO MAINTAIN CIRCUIT CONTINUITY.


|                                           |                              |                 |           |                                                   |                                                                 |         |  |                                                   |           |                    |                 |              |
|-------------------------------------------|------------------------------|-----------------|-----------|---------------------------------------------------|-----------------------------------------------------------------|---------|--|---------------------------------------------------|-----------|--------------------|-----------------|--------------|
| FILE NAME =                               | USER NAME = mazag            | DESIGNED -      | REVISED - | STATE OF ILLINOIS<br>DEPARTMENT OF TRANSPORTATION | REMOVAL OF ELECTRICAL LIGHTING FROM SIGN STRUCTURE SHEET 2 OF 2 |         |  | F.A.<br>RTE.                                      | SECTION   | COUNTY             | TOTAL<br>SHEETS | SHEET<br>NO. |
| as\pwr\work\pwr\doc\mazag\td8267541\be588 | gn                           | DRAWN -         | REVISED - |                                                   | SPAN TYPE                                                       |         |  |                                                   |           |                    |                 |              |
|                                           | PLOT SCALE = 188.8888' / in. | CHECKED -       | REVISED - |                                                   | SCALE: NONE                                                     |         |  |                                                   |           |                    |                 |              |
|                                           | PLOT DATE = 18/18/2014       | DATE - 08-20-13 | REVISED - |                                                   | SHEET NO. 2 OF 2 SHEETS                                         |         |  |                                                   |           |                    |                 |              |
|                                           |                              |                 |           |                                                   | STA.                                                            | TO STA. |  |                                                   |           |                    |                 |              |
|                                           |                              |                 |           |                                                   |                                                                 |         |  | 90/94                                             | 2012-0521 | COOK               | 165             | 105          |
|                                           |                              |                 |           |                                                   |                                                                 |         |  | BE-610                                            |           | CONTRACT NO. 60T93 |                 |              |
|                                           |                              |                 |           |                                                   |                                                                 |         |  | FED. ROAD DIST. NO. 1 ILL. PROJ. FED. AID PROJECT |           |                    |                 |              |

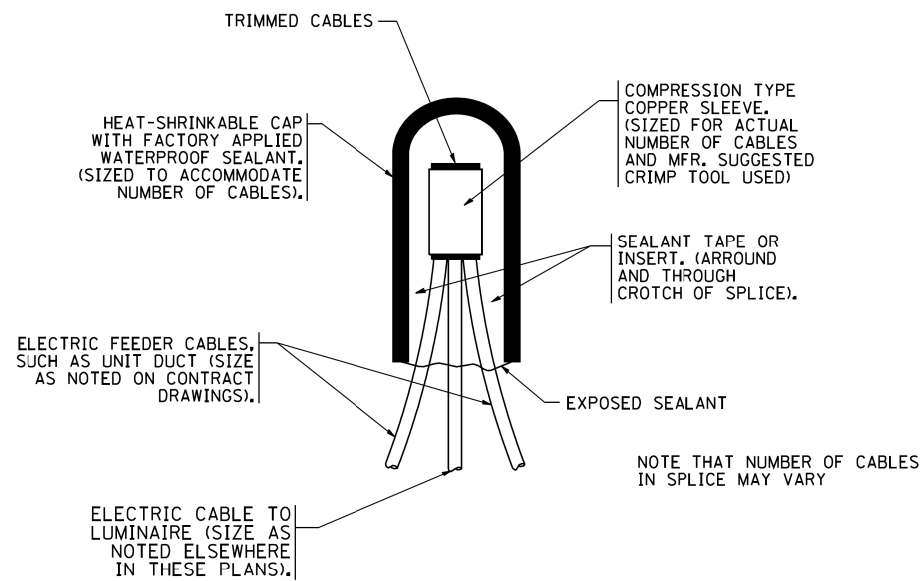

TYPICAL SPLICE DETAIL  
N.T.S.

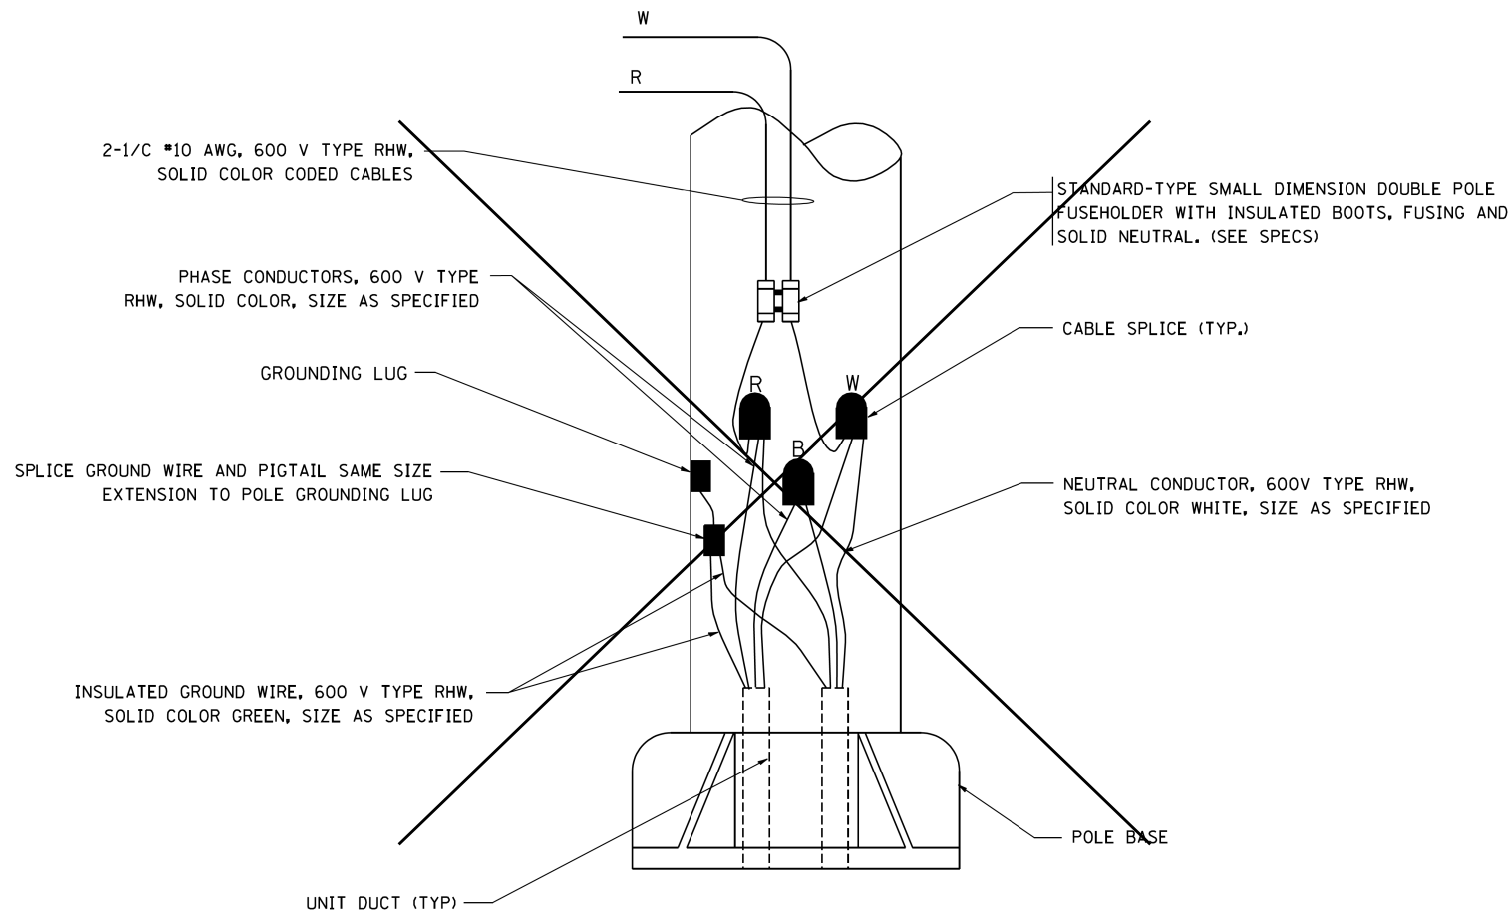


POLE WIRING DETAIL  
N.T.S.


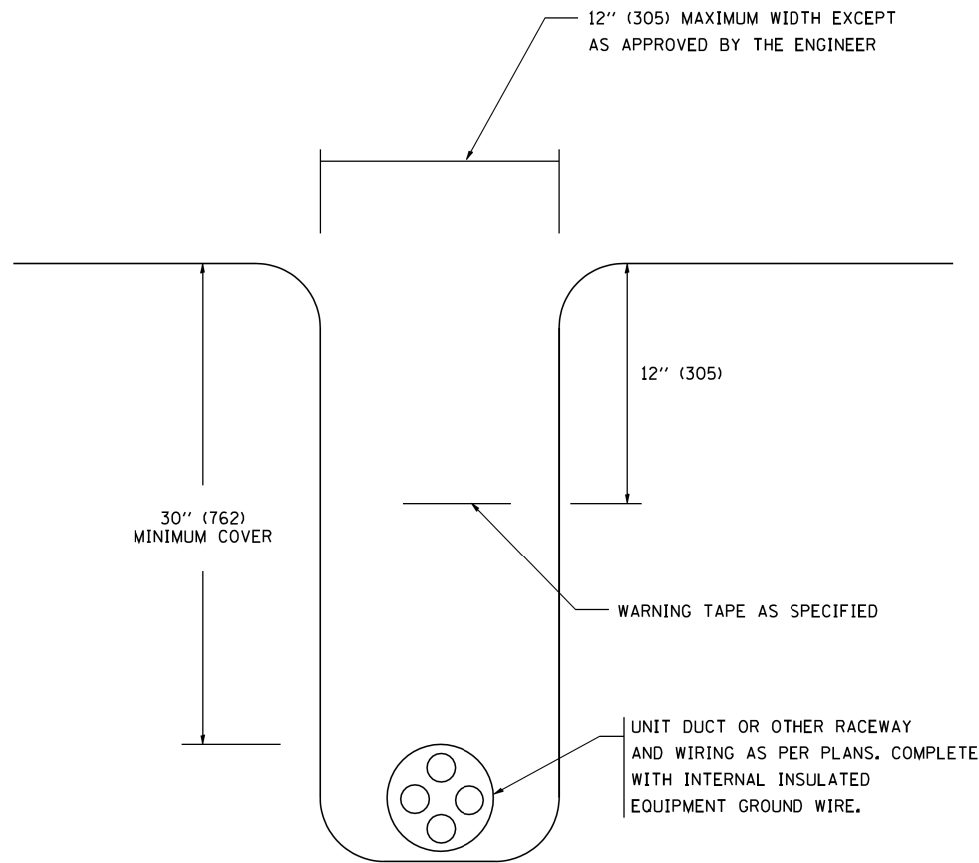


TYPICAL WIRING IN TRENCH DETAIL  
N.T.S.

|                                           |                             |            |                    |                                                   |                                     |             |             |             |           |                                                     |              |           |
|-------------------------------------------|-----------------------------|------------|--------------------|---------------------------------------------------|-------------------------------------|-------------|-------------|-------------|-----------|-----------------------------------------------------|--------------|-----------|
| FILE NAME =<br>W:\diststd\22x34\be702.dgn | USER NAME = geglienobt      | DESIGNED - | REVISED - 08-08-03 | STATE OF ILLINOIS<br>DEPARTMENT OF TRANSPORTATION | MISC. ELECTRICAL DETAILS<br>SHEET A |             |             | F.A.I. RTE. | SECTION   | COUNTY                                              | TOTAL SHEETS | SHEET NO. |
|                                           |                             | DRAWN -    | REVISED -          |                                                   |                                     |             |             | 90/94       | 2012-0521 | COOK                                                | 165          | 106       |
|                                           | PLOT SCALE = 50.000 ' / IN. | CHECKED -  | REVISED -          |                                                   |                                     |             |             | BE-702      |           | CONTRACT NO. 60T93                                  |              |           |
|                                           | PLOT DATE = 1/4/2008        | DATE -     | REVISED -          |                                                   | SCALE: NONE                         | SHEET NO. 1 | OF 1 SHEETS | STA.        | TO STA.   | FED. ROAD DIST. NO. 1   ILLINOIS   FED. AID PROJECT |              |           |

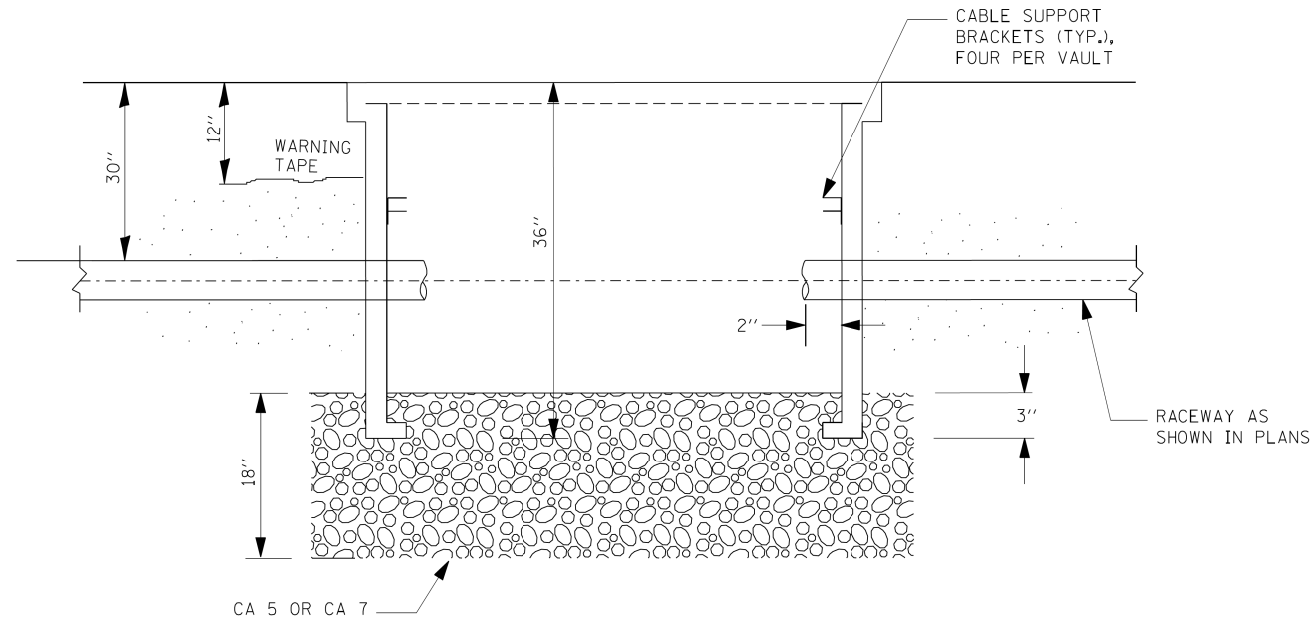


SECTION A-A

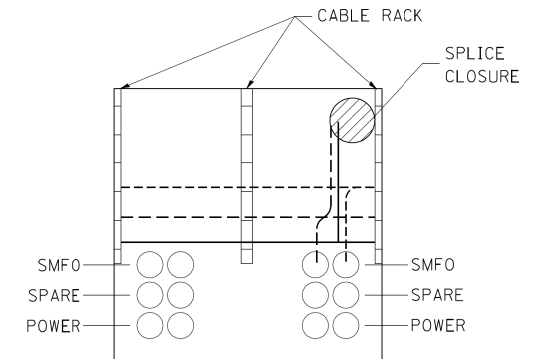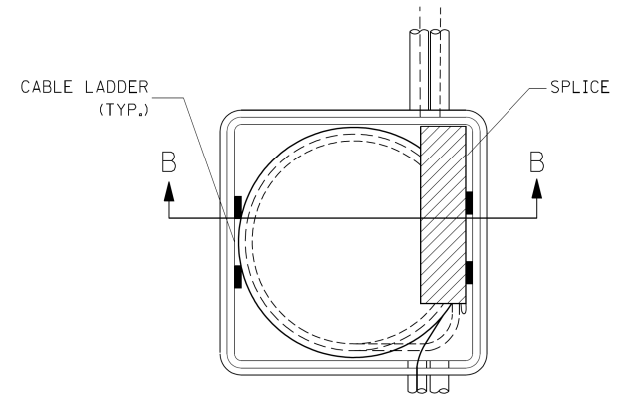


SECTION B-B

NOTES:

- BOX SHALL HAVE AN OPEN BASE.
- COVER SHALL WITHSTAND A 22,500/33,750 DESIGN/TEST LOADING AND SHALL LOCK.
- ALL OPENINGS IN STRUCTURE MUST BE MACHINED AT TIME OF FABRICATION OR PUNCH DRIVEN AT TIME OF PLACEMENT. IN ACCORDANCE WITH MANUFACTURER RECOMMENDATIONS.
- FIELD PLACEMENT OF COMMUNICATIONS VAULT SHALL BE AS DIRECTED BY THE ENGINEER.
- ALL DIMENSIONS ARE MINIMUM AND A LARGER SIZE HANDHOLE MAY BE USED, WITH THE APPROVAL OF THE ENGINEER, TO FACILITATE USING A MANUFACTURER'S STANDARD PRODUCT.

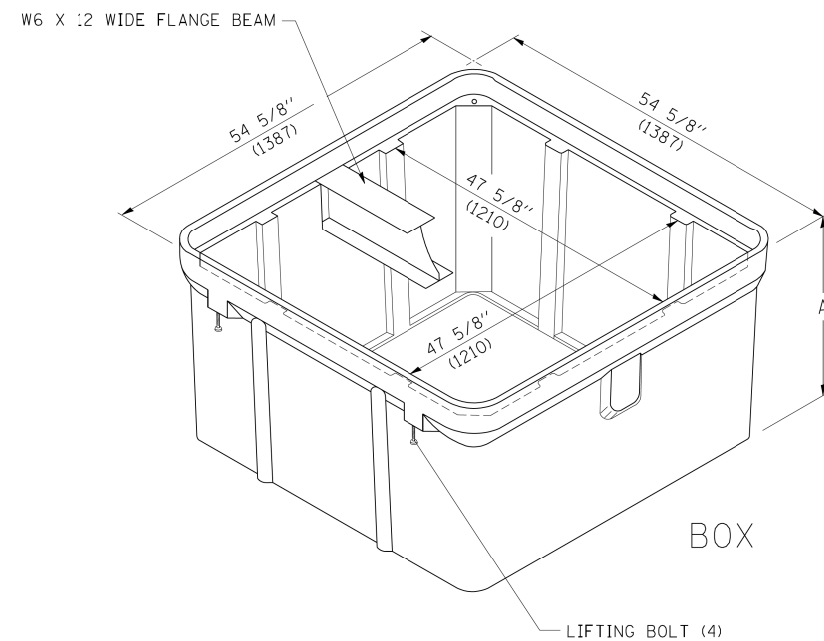


ISOMETRIC

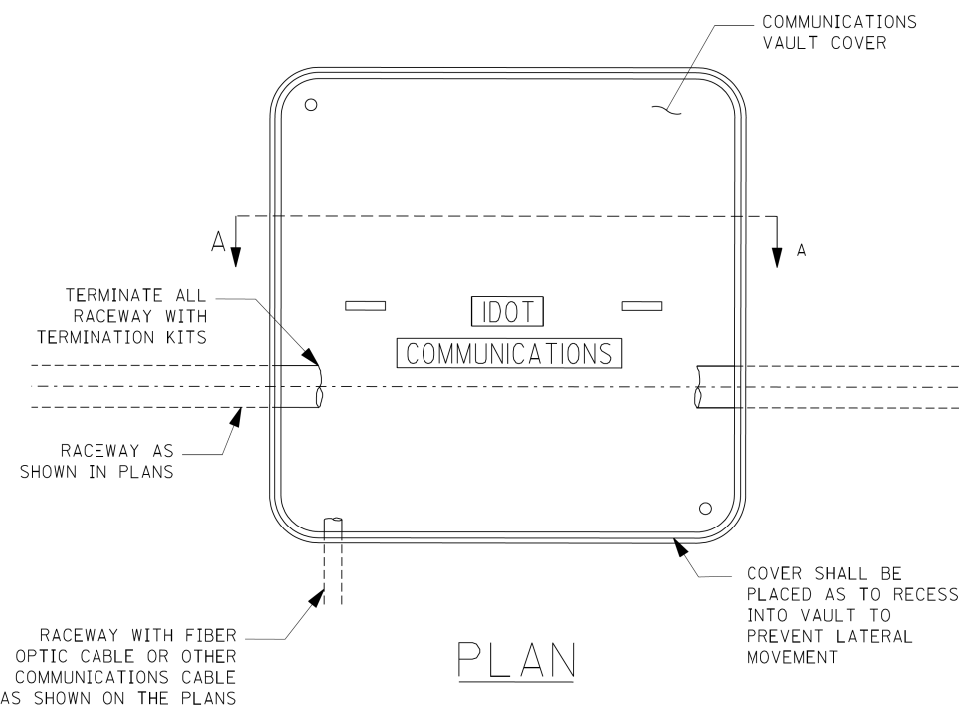


PLAN


|                                                               |                              |                 |           |                                                   |                                                     |           |                    |        |                |           |        |                 |              |
|---------------------------------------------------------------|------------------------------|-----------------|-----------|---------------------------------------------------|-----------------------------------------------------|-----------|--------------------|--------|----------------|-----------|--------|-----------------|--------------|
| FILE NAME =<br><br>c:\pwwork\PW\IDOT\LEISA\d0108315\be705.dgn | USER NAME = lrysa            | DESIGNED -      | REVISED - | STATE OF ILLINOIS<br>DEPARTMENT OF TRANSPORTATION | COMMUNICATIONS VAULT, COMPOSITE CONCRETE            |           |                    |        | F.A.I.<br>RTE. | SECTION   | COUNTY | TOTAL<br>SHEETS | SHEET<br>NO. |
|                                                               |                              | DRAWN -         | REVISED - |                                                   |                                                     |           |                    |        | 90/94          | 2012-0521 | COOK   | 165             | 107          |
|                                                               | PLOT SCALE = 50.0000 ' / IN. | CHECKED -       | REVISED - |                                                   | BE-705                                              |           | CONTRACT NO. 60T93 |        |                |           |        |                 |              |
|                                                               | PLOT DATE = 3/29/2010        | DATE - 03-22-10 | REVISED - |                                                   | SCALE: NONE                                         | SHEET NO. | OF                 | SHEETS | STA.           | TO STA.   |        |                 |              |
|                                                               |                              |                 |           |                                                   | FED. ROAD DIST. NO. 1   ILLINOIS   FED. AID PROJECT |           |                    |        |                |           |        |                 |              |

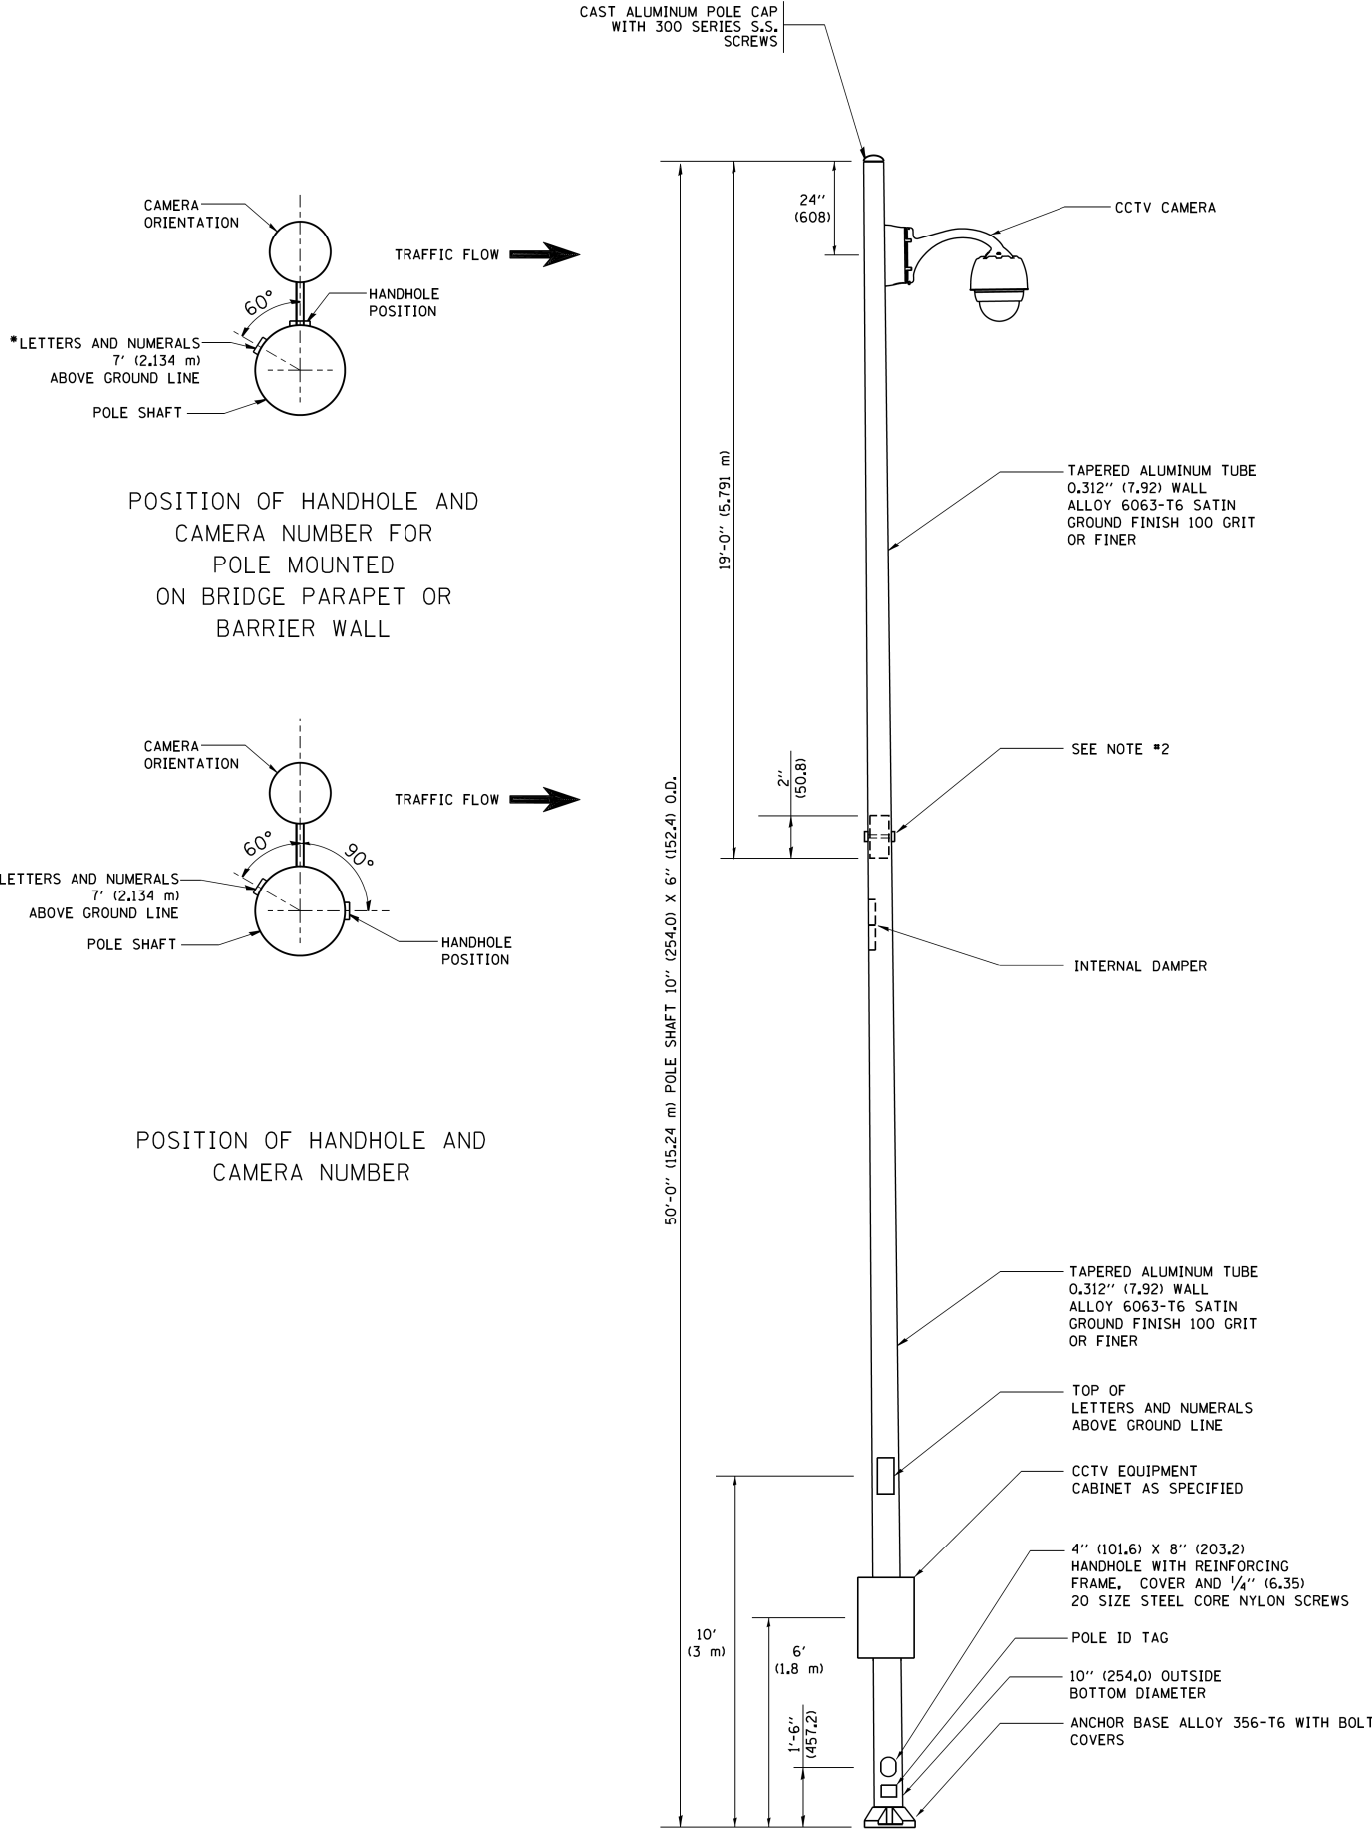


- NOTES:**
1. ALL DIMENSIONS ARE IN INCHES (MILLIMETERS) UNLESS OTHERWISE SHOWN.
  2. TWO PIECE SHAFT WILL BE MATCHED MARKED AND INTERCHANGEABLE BETWEEN DIFFERENT UNITS. FIELD DRILLING OF THE HOLES WILL NOT BE ALLOWED.
  3. THE POLE WILL MEET AASHTO DESIGN CRITERIA AS SPECIFIED.
  4. THE INSTALLING CONTRACTOR WILL PROVIDE A UL LISTED GROUNDING CONNECTOR, BURNDY K2C23, T&B SP4DL OR APPROVED EQUAL.
  5. POLES WILL BE INSTALLED IN ACCORDANCE TO MANUFACTURER'S INSTRUCTIONS.
  6. POLES WILL BE SET PLUMB ON THE FOUNDATION WITHOUT THE USE OF LEVELING NUTS, WASHERS OR SHIMS.

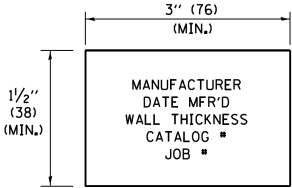

POLE ID TAG  
NTS

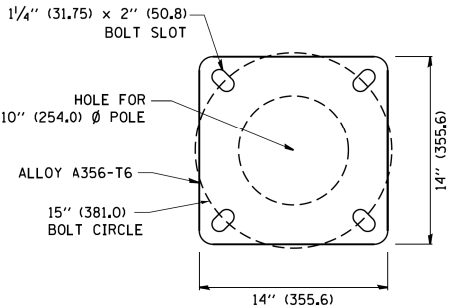

POLE BASE PLATE DETAIL  
15 INCH (381.0) BOLT CIRCLE

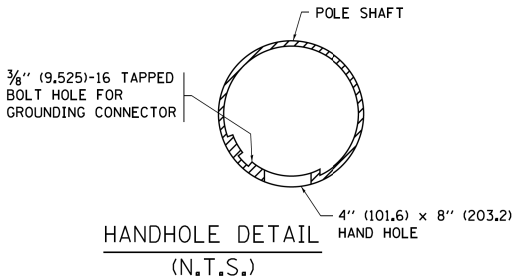


|                                                             |                             |            |                               |                                                   |                                                        |                         |      |                    |                                                 |        |              |           |
|-------------------------------------------------------------|-----------------------------|------------|-------------------------------|---------------------------------------------------|--------------------------------------------------------|-------------------------|------|--------------------|-------------------------------------------------|--------|--------------|-----------|
| FILE NAME =<br>c:\pwork\pwork\drivakosgn\d0108315\be000.dgn | USER NAME = drivakosgn      | DESIGNED - | REVISED - R. TOMSONS 09-06-00 | STATE OF ILLINOIS<br>DEPARTMENT OF TRANSPORTATION | CCTV CAMERA STRUCTURE<br>50' (15.24 m) MOUNTING HEIGHT |                         |      | F.A.I. RTE.        | SECTION                                         | COUNTY | TOTAL SHEETS | SHEET NO. |
|                                                             | PLOT SCALE = 50.000 ' / in. | DRAWN -    | REVISED - R. TOMSONS 09-03-03 |                                                   |                                                        |                         |      | 90/94              | 2012-0521                                       | COOK   | 165          | 108       |
|                                                             | PLOT DATE = 6/5/2014        | CHECKED -  | REVISED - R. TOMSONS 02-27-13 |                                                   | BE-1000                                                |                         |      | CONTRACT NO. 60T93 |                                                 |        |              |           |
|                                                             |                             | DATE -     | REVISED - R. TOMSONS 05-04-14 |                                                   | SCALE: NONE                                            | SHEET NO. 1 OF 1 SHEETS | STA. | TO STA.            | FED. ROAD DIST. NO. 1 ILLINOIS FED. AID PROJECT |        |              |           |




CCTV CAMERA POLE FOUNDATION DEPTH TABLE


| SOIL CONDITIONS                     | DESIGN DEPTH "D" OF FOUNDATION |
|-------------------------------------|--------------------------------|
| SOFT CLAY<br>Qu = 0.375 TON/SQ. FT. | 13'-0" (3.96 m)                |
| MEDIUM CLAY<br>Qu = 0.75 TON/SQ.FT  | 9'-6" (2.09 m)                 |
| STIFF CLAY<br>Qu = 1.50 TON/SQ. FT. | 7'-0" (2.13 m)                 |
| LOOSE SAND<br>φ = 34°               | 9'-0" (2.74 m)                 |
| MEDIUM SAND<br>φ = 37.5°            | 8'-3" (2.52 m)                 |
| DENSE SAND<br>φ = 40°               | 7'-9" (2.36 m)                 |

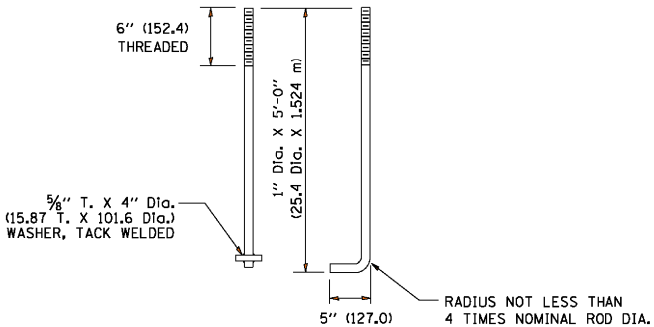


ANCHOR ROD DETAIL

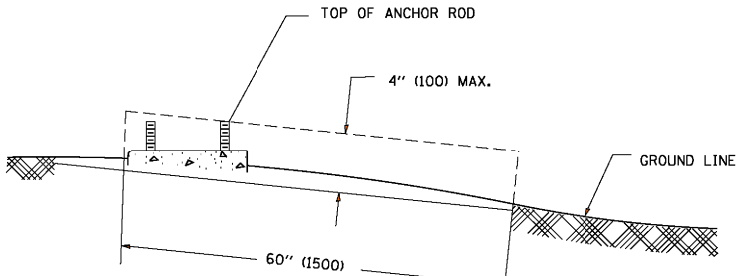


FOUNDATION EXTENSION DETAIL

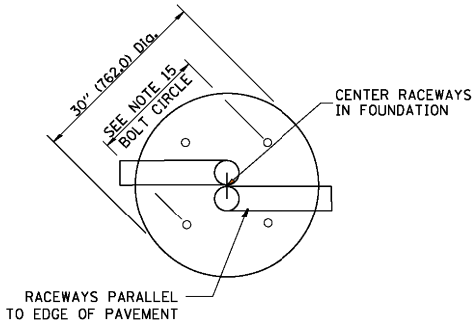

TOP VIEW

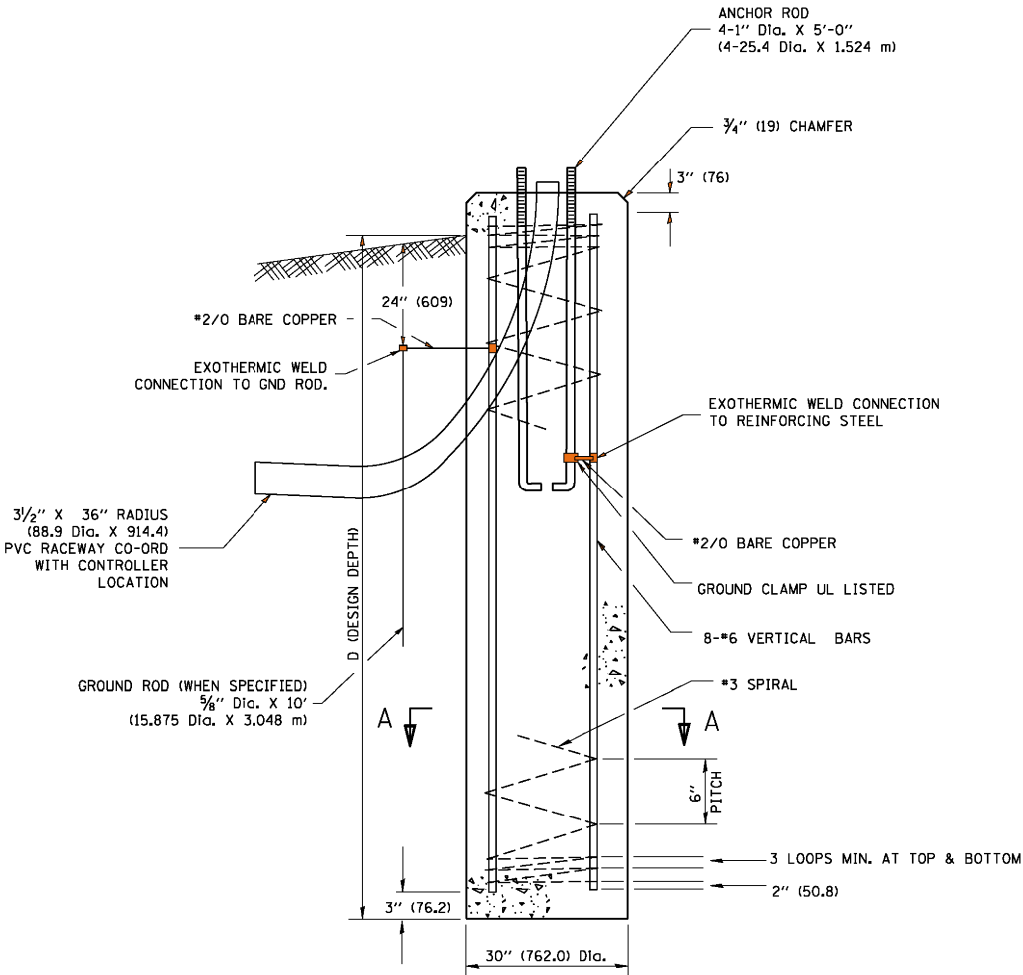


FOUNDATION DETAIL

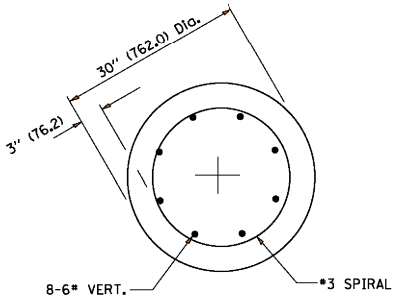

SECTION A-A


NOTES

- ALL DIMENSIONS ARE IN INCHES (MILLIMETERS) UNLESS OTHERWISE SHOWN.
- THE ANCHOR RODS AND RACEWAYS SHALL BE PROPERLY SECURED IN PLACE BEFORE THE CONCRETE IS PLACED.
- THE FOUNDATION SHALL NOT PROTRUDE MORE THAN 100MM (4 IN.) ABOVE THE FINISHED GRADE WITHIN A 60 IN. (1.5 m) CHORD ACROSS THE FOUNDATION, WITH ANCHOR RODS INCLUDED, IN ACCORDANCE WITH AASHTO GUIDELINES. IF THE FOUNDATION HEIGHT, INCLUDING ANCHOR RODS, EXTENDS BEYOND THESE SPECIFIED LIMITS, THE FOUNDATION SHALL BE REPLACED AT THE CONTRACTOR'S EXPENSE. SEE FOUNDATION EXTENSION DETAIL.
- THE HOLE FOR THE FOUNDATION SHALL BE MADE BY DRILLING WITH AN AUGER, OF THE SAME DIAMETER AS THE FOUNDATION. IF SOIL CONDITIONS REQUIRE THE USE OF A LINER TO FORM THE HOLE, THE LINER SHALL BE WITHDRAWN AS THE CONCRETE IS DEPOSITED.
- THE TOP OF THE FOUNDATION SHALL BE CONSTRUCTED LEVEL. A LINER OR FORM SHALL BE USED TO PRODUCE A UNIFORM SMOOTH SIDE TO THE TOP OF THE FOUNDATION. FOUNDATION TOP SHALL BE CHAMFERED 3/4-IN. (20 mm).
- THE CONCRETE SHALL BE CLASS SI. CONCRETE SHALL CURE ACCORDING TO ARTICLE 1020.13 BEFORE LIGHT POLES ARE INSTALLED.
- THE ANCHOR ROD SHALL BE A HOOK ROD TYPE. COLD BENDING OF THE ANCHOR ROD WILL NOT BE ALLOWED. THE RADIUS OF THE HOOK BEND SHALL NOT BE LESS THAN 4 TIMES THE NOMINAL DIAMETER OF THE ANCHOR ROD. A TACK WELDED ANCHOR ROD MAY BE SUBSTITUTED WITH THE APPROVAL OF THE ENGINEER.
- THE ANCHOR RODS SHALL BE ACCORDING TO ASTM F1554 GRADE 725 (GRADE 105). NUTS SHALL BE HEXAGON NUTS ACCORDING TO ASTM A 194 2H OR ASTM A 563 DH, AND WASHERS SHALL BE ACCORDING TO ASTM F 436.
- ANCHOR RODS, NUTS AND WASHERS SHALL BE COMPLETELY GALVANIZED BY EITHER THE HOT-DIPPED PROCESS CONFORMING WITH AASHTO M 232, THE MECHANICAL PLATING METHOD CONFORMING TO AASHTO M 298, CLASS 50 WITH A MAXIMUM COATING THICKNESS OF 150 UM(6 MILS) OR THE ELECTROLYTIC PROCESS ACCORDING TO ASTM F 1136.
- THE ANCHOR RODS SHALL BE THREADED A MINIMUM OF 6 INCHES (150 mm) WITH A MINIMUM OF 3 INCHES (75 mm) OF THREADED ANCHOR ROD EMBEDDED IN THE FOUNDATION.
- ANCHOR RODS SHALL PROJECT 2 3/4" (69.9 mm) ABOVE THE TOP OF THE FOUNDATION. IF BREAKAWAY COUPLINGS ARE SPECIFIED, THE CONTRACTOR SHALL CAREFULLY COORDINATE THE ANCHOR ROD PROJECTION WITH THE INSTALLATION REQUIREMENTS OF THE BREAKAWAY COUPLINGS.
- THE CONTRACTOR SHALL USE A #3 SPIRAL AT 6" (152.4 mm) PITCH OR MAY SUBSTITUTE #3 TIES AT 12" (304.8 mm) O.C. WITH THE APPROVAL OF THE ENGINEER.
- THE CABLE TRENCHES AND FOUNDATION SHALL BE BACK FILLED AND COMPACTED AS SPECIFIED BEFORE THE LIGHT POLE IS ERECTED.
- THE RACEWAYS SHALL PROJECT 1" (25.4 mm) ABOVE THE TOP OF THE FOUNDATION.
- ANCHOR ROD BOLT CIRCLE TO BE COORDINATED WITH CAMERA STRUCTURE

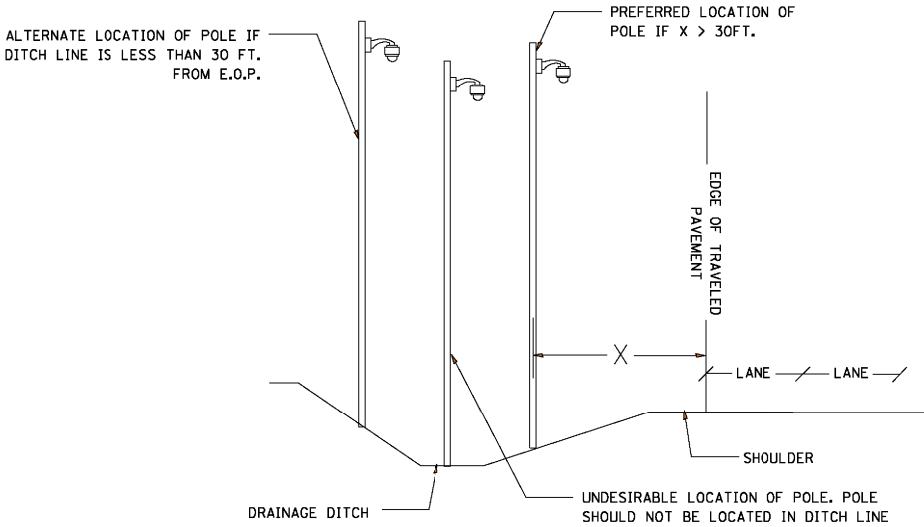

CAMERA POLE PLACEMENT


|                                                              |                             |                    |           |                                                   |                                                                    |             |             |                                                 |           |                    |              |           |
|--------------------------------------------------------------|-----------------------------|--------------------|-----------|---------------------------------------------------|--------------------------------------------------------------------|-------------|-------------|-------------------------------------------------|-----------|--------------------|--------------|-----------|
| FILE NAME =<br>c:\pwwork\pwwork\footemj\d0108315\bel1001.dgn | USER NAME = footemj         | DESIGNED - TOMSONS | REVISED - | STATE OF ILLINOIS<br>DEPARTMENT OF TRANSPORTATION | CCTV CAMERA STRUCTURE FOUNDATION<br>50' (15 - 24m) MOUNTING HEIGHT |             |             | F.A.I. RTE.                                     | SECTION   | COUNTY             | TOTAL SHEETS | SHEET NO. |
|                                                              |                             | DRAWN -            | REVISED - |                                                   |                                                                    |             |             | 90/94                                           | 2012-0521 | COOK               | 165          | 109       |
|                                                              | PLOT SCALE = 50.0001' / in. | CHECKED -          | REVISED - |                                                   |                                                                    |             |             | BE-1001                                         |           | CONTRACT NO. 60T93 |              |           |
|                                                              | PLOT DATE = 4/3/2013        | DATE - 03-11-13    | REVISED - |                                                   |                                                                    |             |             | FED. ROAD DIST. NO. 1 ILLINOIS FED. AID PROJECT |           |                    |              |           |
|                                                              |                             |                    |           |                                                   | SCALE: NONE                                                        | SHEET NO. 1 | OF 1 SHEETS | STA.                                            | TO STA.   |                    |              |           |

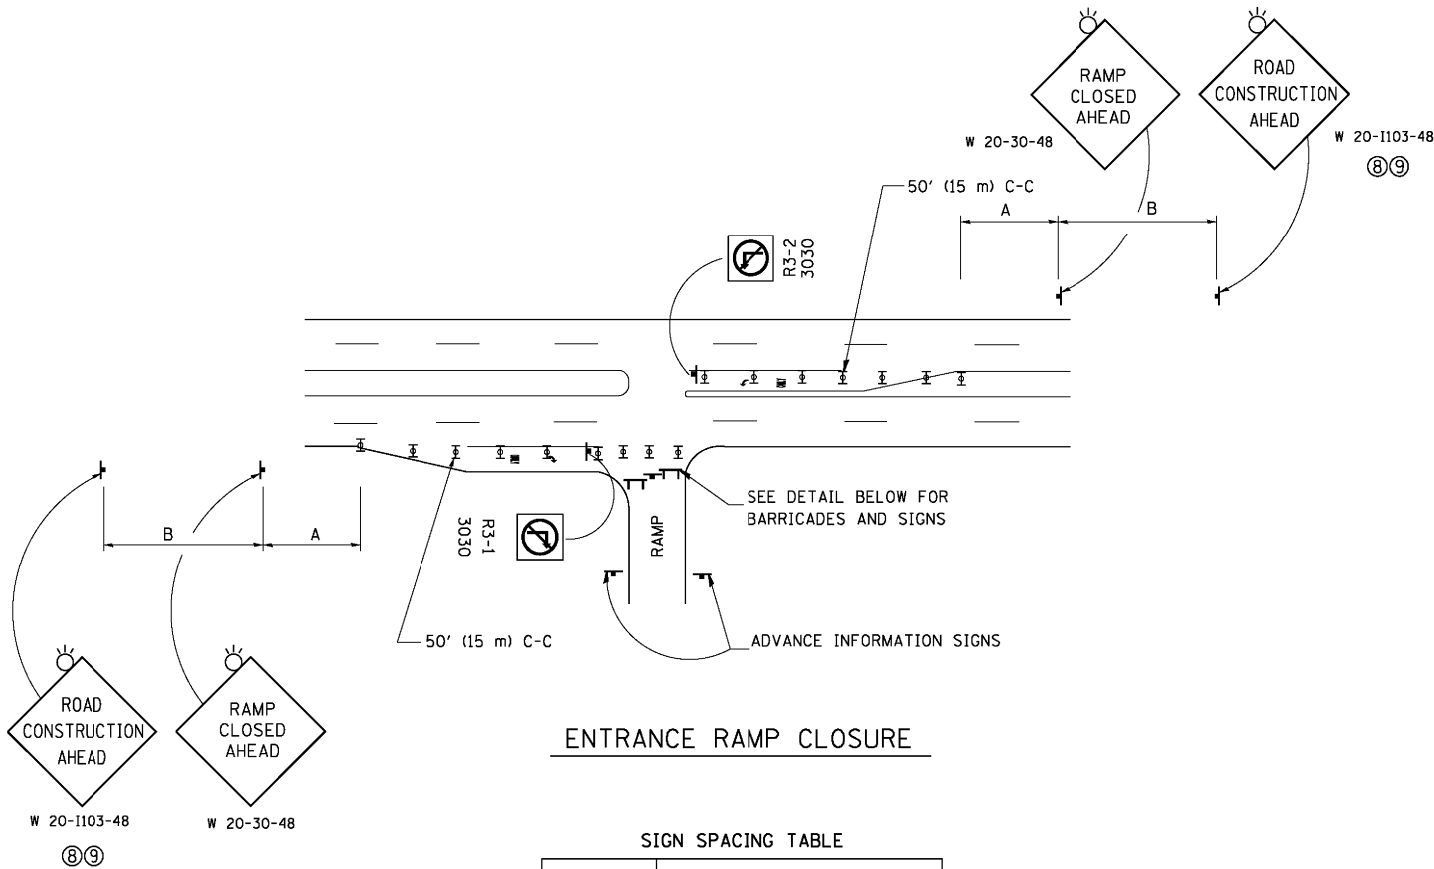

ENTRANCE RAMP CLOSURE

| FACILITY                | DISTANCE BETWEEN SIGNS |                  |
|-------------------------|------------------------|------------------|
|                         | A                      | B                |
| EXPRESSWAY<br>>24 HOURS | 1000'<br>(300 m)       | 1500'<br>(450 m) |
| EXPRESSWAY<br>≤24 HOURS | 500'<br>(150 m)        | 500'<br>(150 m)  |
| ARTERIAL<br>55 MPH      | 500'<br>(150 m)        | 500'<br>(150 m)  |
| ARTERIAL<br>50-45 MPH   | 350'<br>(100 m)        | 350'<br>(100 m)  |
| ARTERIAL<br><45 MPH     | 200'<br>(60 m)         | 200'<br>(60 m)   |


DISTANCES MAY BE SHORTENED DEPENDING UPON THE PROXIMITY OF ADJACENT RAMPS OR INTERSECTIONS.

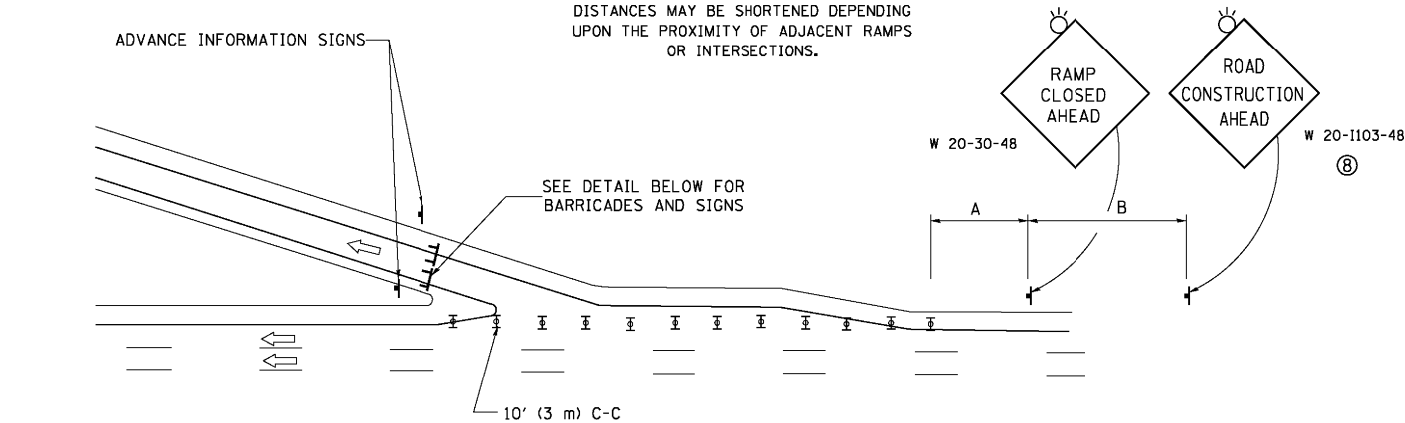


EXIT RAMP CLOSURE

SYMBOLS


- TYPE II BARRICADE OR DRUM WITH STEADY BURN MONO-DIRECTIONAL LIGHT
- TYPE III BARRICADE WITH 2 FLASHING LIGHTS

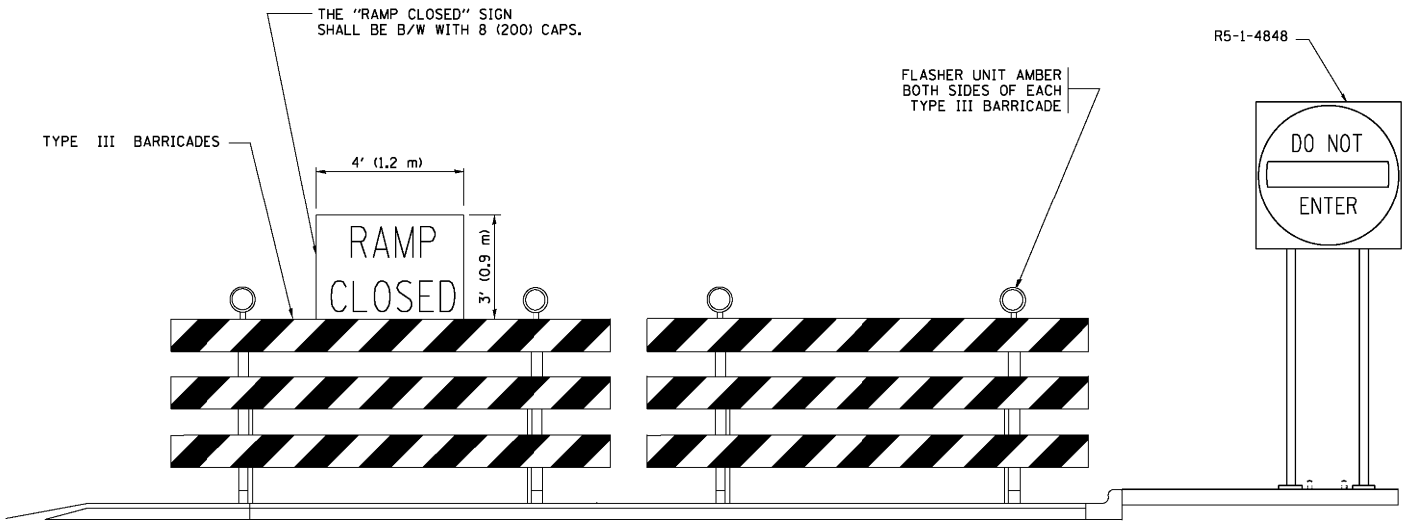

DETAIL FOR REQUIRED BARRICADES & SIGNS

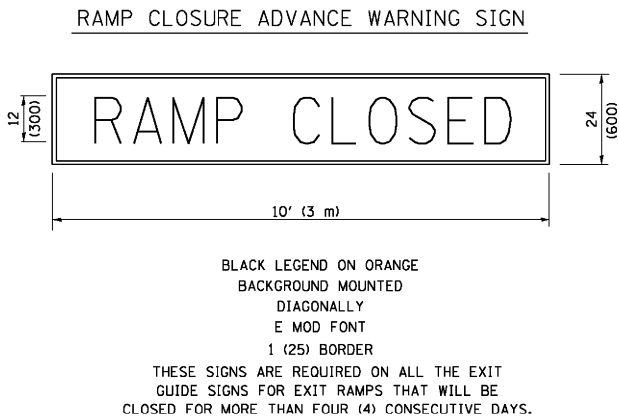

RAMP CLOSURE ADVANCE INFORMATION SIGN

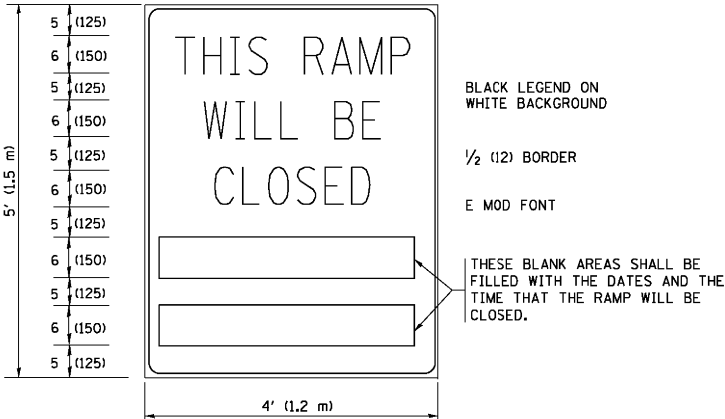

THESE SIGNS ARE REQUIRED ON BOTH SIDES OF THE RAMP, MINIMUM OF 1 WEEK IN ADVANCE OF THE CLOSURE.  
THESE SIGNS SHALL BE FABRICATED AND PAID FOR ACCORDING TO THE TEMPORARY INFORMATION SIGNING SPECIAL PROVISION

GENERAL NOTES:


- CONES MAY BE SUBSTITUTED FOR DRUMS OR TYPE II BARRICADES DURING DAY OPERATIONS. CONES SHALL BE A MINIMUM OF 28 (700) HIGH.
- STEADY BURN LIGHTS WILL NOT BE REQUIRED FOR DAY OPERATIONS.
- A FLAGGER SHALL BE POSITIONED AT EACH CLOSED RAMP THAT IS OPEN TO CONSTRUCTION VEHICLES, PRECEDED BY A W20-7 FLAGGER WARNING SIGN.
- ALL ROUTE MARKERS AND TRAILBLAZER ASSEMBLIES WHICH DIRECT MOTORISTS TO A CLOSED ENTRANCE RAMP SHALL BE COVERED WHEN THE RAMP IS CLOSED FOR MORE THAN FOUR (4) DAYS.
- THE SIGNING AND BARRICADING WHICH IS REQUIRED BY THIS DETAIL SHALL BE INCLUDED IN THE COST OF TRAFFIC CONTROL AND PROTECTION (EXPRESSWAYS).
- AUTHORIZATION FROM THE DISTRICT'S BUREAU OF TRAFFIC IS REQUIRED FOR ALL RAMP CLOSURES.
- THE RAMP CLOSURE ADVANCE INFORMATION SIGNS SHALL BE ERECTED IF THE CLOSURE TIME EXCEEDS TWENTY-FOUR (24) HOURS. ADDITIONAL ADVANCE WARNING SIGNS ON EXIT GUIDE SIGNING WILL BE REQUIRED FOR EXIT RAMP CLOSURES THAT EXCEED FOUR (4) DAYS IN LENGTH.
- ROAD CONSTRUCTION AHEAD SIGNS MAY BE OMITTED WHEN THIS DETAIL IS USED IN CONJUNCTION WITH OTHER TRAFFIC CONTROL THAT ALREADY INCLUDES A ROAD CONSTRUCTION AHEAD SIGN.
- ARTERIAL ROAD CONSTRUCTION AHEAD SIGNS SHALL BE INSTALLED ON THE LEFT SIDE OF TRAFFIC IF THE MEDIAN IS MORE THAN 10 FT WIDE.

ALL DIMENSIONS ARE IN INCHES (MILLIMETERS) UNLESS OTHERWISE SHOWN.


|                                               |                            |                |                     |                                                   |                                           |                 |                         |                    |                 |                                                     |
|-----------------------------------------------|----------------------------|----------------|---------------------|---------------------------------------------------|-------------------------------------------|-----------------|-------------------------|--------------------|-----------------|-----------------------------------------------------|
| FILE NAME =                                   | USER NAME = footemj        | DESIGNED - DWS | REVISED - JAF 02-06 | STATE OF ILLINOIS<br>DEPARTMENT OF TRANSPORTATION | ENTRANCE AND EXIT RAMP<br>CLOSURE DETAILS | F.A.I.-<br>RTE. | SECTION                 | COUNTY             | TOTAL<br>SHEETS | SHEET<br>NO.                                        |
| et\pw_work\pwi\dot\footemj\ad0108315\te08.dgn |                            | DRAWN -        | REVISED - SPB 01-07 |                                                   |                                           | 90/94           | 2012-0521               | COOK               | 165             | 110                                                 |
|                                               | PLOT SCALE = 50.000' / in. | CHECKED -      | REVISED - SPB 12-09 |                                                   |                                           | TC-08           |                         | CONTRACT NO. 60T93 |                 |                                                     |
|                                               | PLOT DATE = 7/8/2013       | DATE - 02-83   | REVISED - MD 06-13  |                                                   |                                           | SCALE: NONE     | SHEET NO. 1 OF 1 SHEETS | STA.               | TO STA.         | FED. ROAD DIST. NO. 1   ILLINOIS   FED. AID PROJECT |



# SINGLE LANE WEAVE

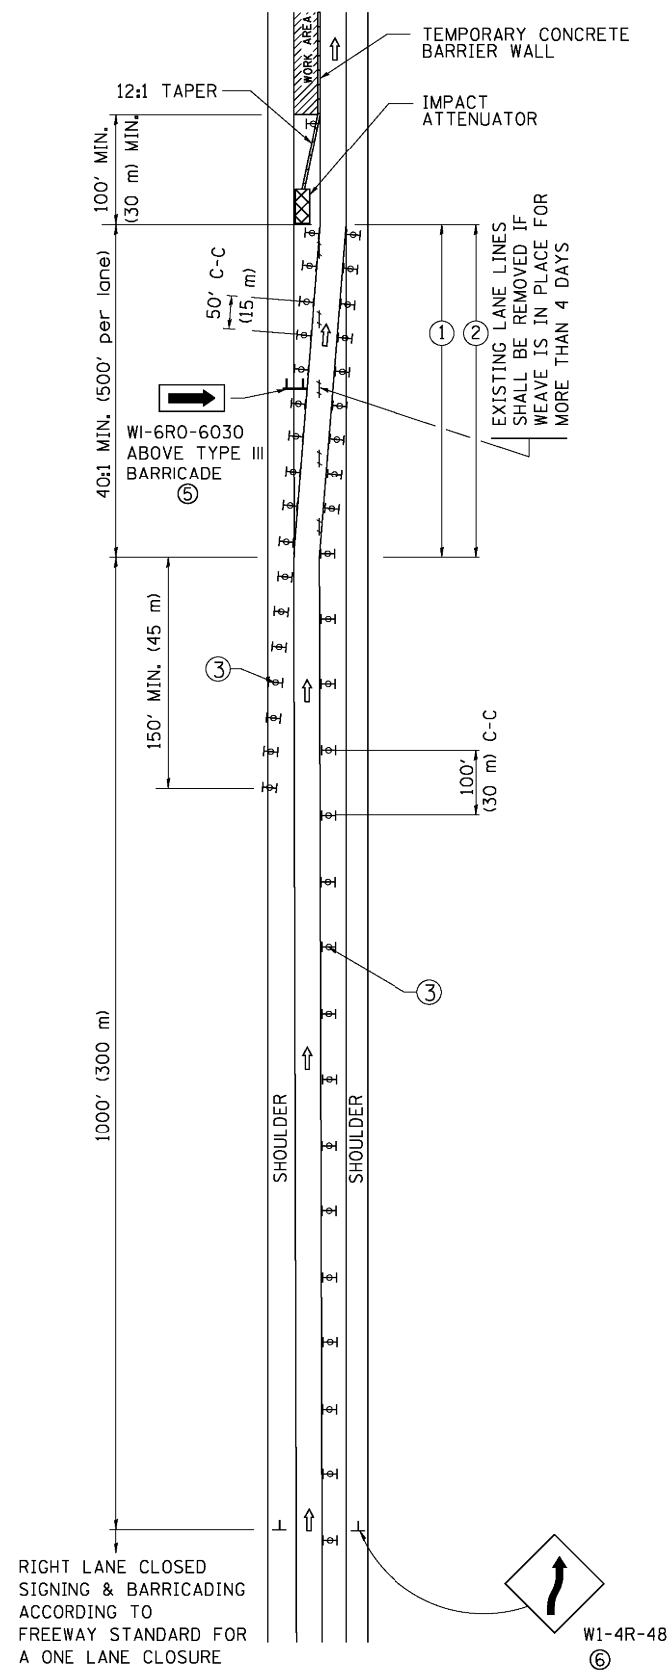

## MULTI-LANE WEAVE

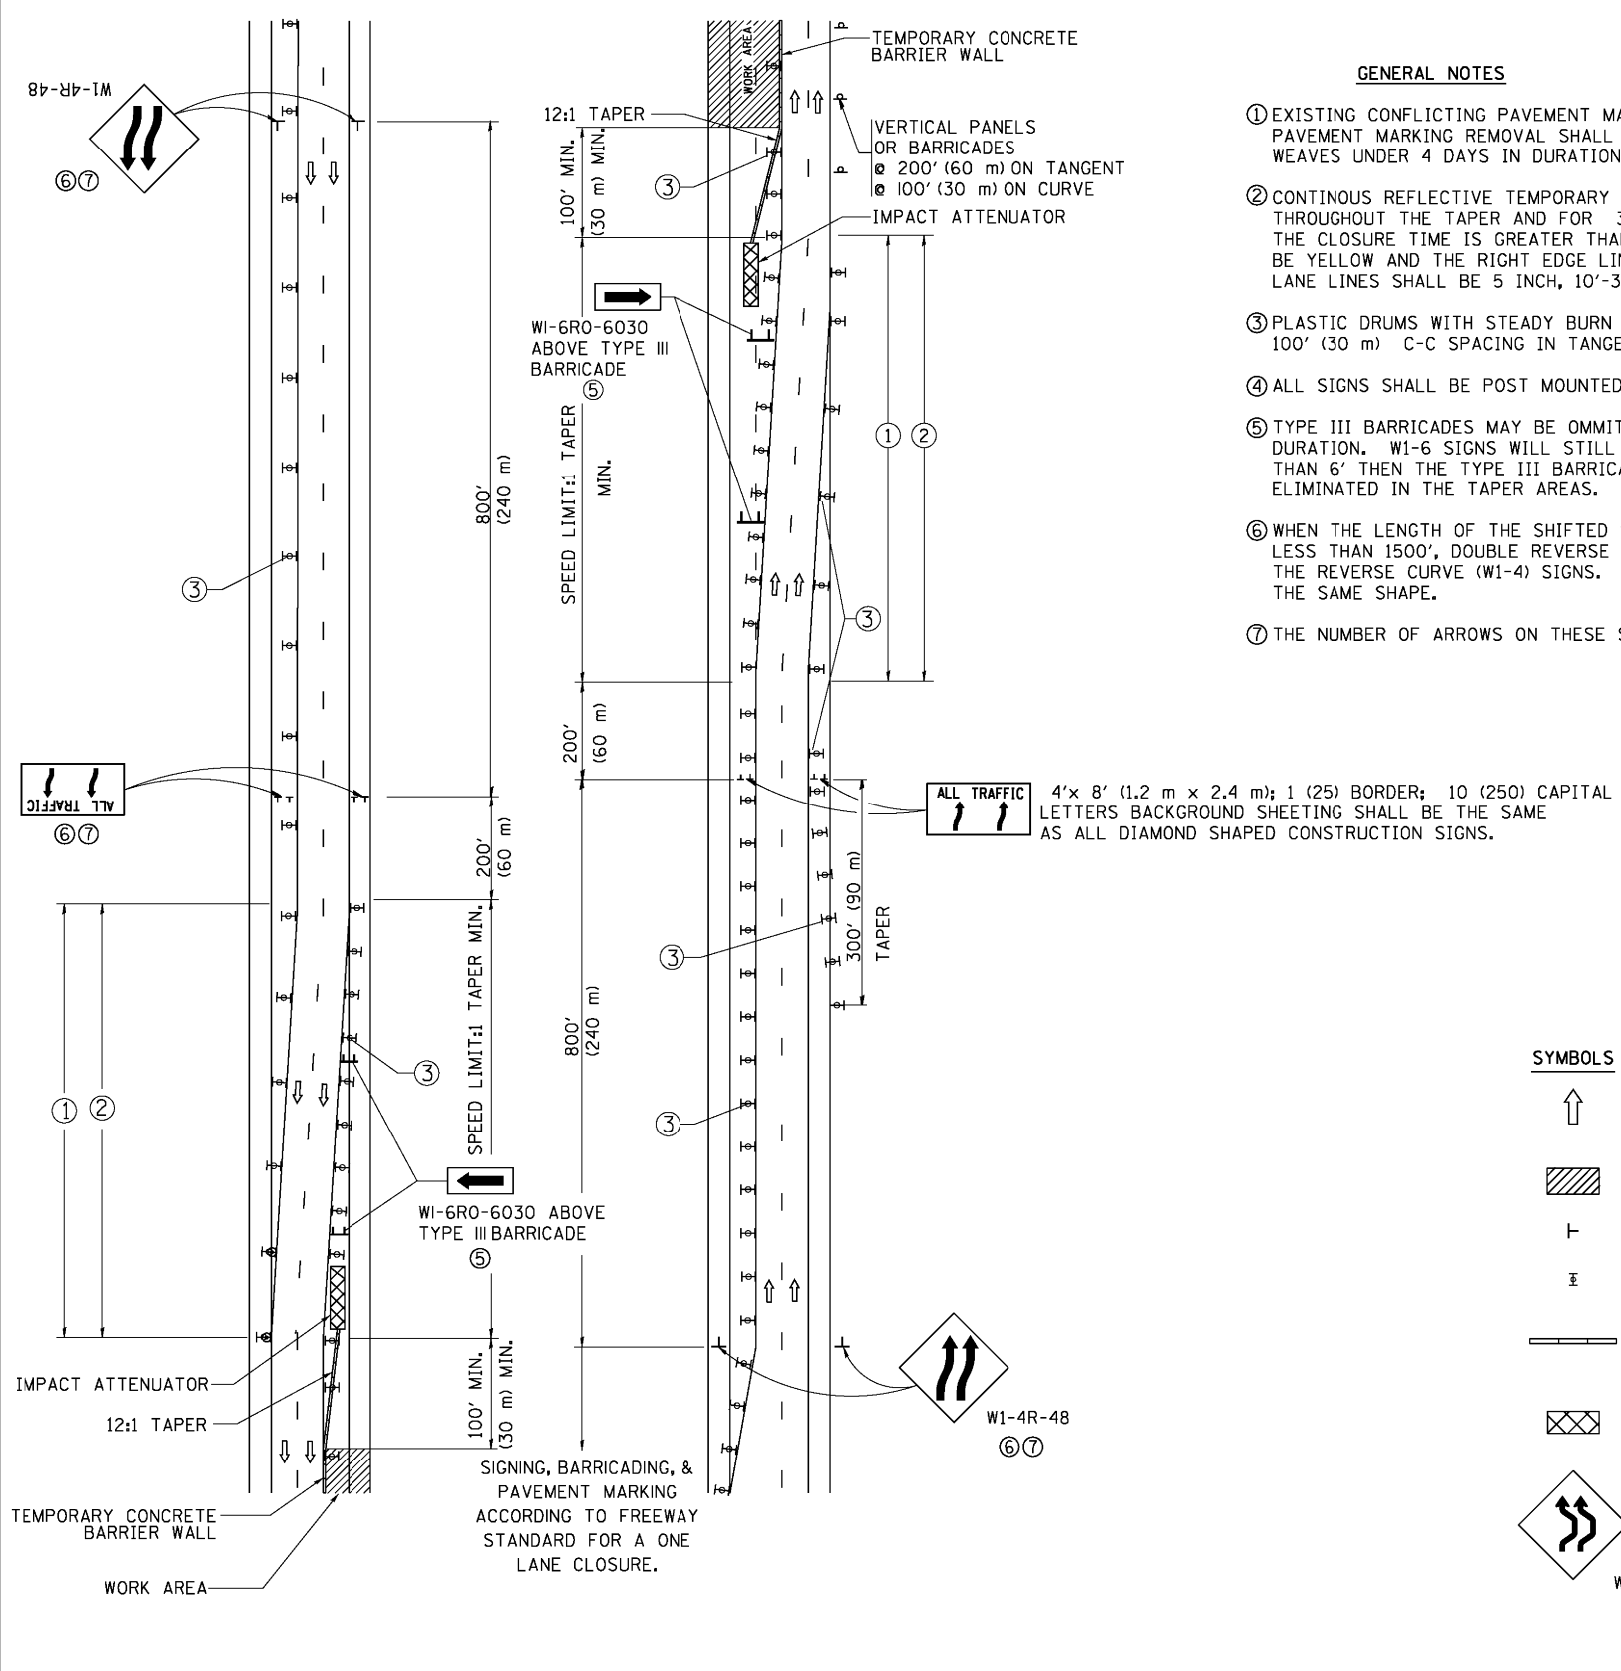

### GENERAL NOTES

- ① EXISTING CONFLICTING PAVEMENT MARKING LINES SHALL BE REMOVED. PAVEMENT MARKING REMOVAL SHALL NOT BE REQUIRED FOR SINGLE LANE WEAVES UNDER 4 DAYS IN DURATION.
- ② CONTINUOUS REFLECTIVE TEMPORARY PAVEMENT MARKING TAPE SHALL BE PLACED THROUGHOUT THE TAPER AND FOR 300' (90 m) ALONG SIDE THE WORK AREA WHERE THE CLOSURE TIME IS GREATER THAN FOURTEEN DAYS. THE LEFT EDGE LINE SHALL BE YELLOW AND THE RIGHT EDGE LINE SHALL BE WHITE. FOR MULTI-LANE WEAVES LANE LINES SHALL BE 5 INCH, 10'-30' (3 m-9 m) SKIP DASH, WHITE.
- ③ PLASTIC DRUMS WITH STEADY BURN LIGHTS AT 50' (15 m) C-C SPACING IN TAPERS AND 100' (30 m) C-C SPACING IN TANGENTS.
- ④ ALL SIGNS SHALL BE POST MOUNTED IF THE CLOSURE TIME EXCEEDS FOUR DAYS.
- ⑤ TYPE III BARRICADES MAY BE OMITTED FOR SINGLE-LANE WEAVES UNDER 24-HOURS IN DURATION. W1-6 SIGNS WILL STILL BE REQUIRED. IF THE WIDTH OF OFFSET IS LESS THAN 6' THEN THE TYPE III BARRICADE WITH ATTACHED ARROW SIGN PANEL CAN BE ELIMINATED IN THE TAPER AREAS.
- ⑥ WHEN THE LENGTH OF THE SHIFTED SEGMENT (DISTANCE BETWEEN WEAVE POINTS) IS LESS THAN 1500', DOUBLE REVERSE CURVE SIGNS (W24-1) SHOULD BE USED INSTEAD OF THE REVERSE CURVE (W1-4) SIGNS. ARROWS ON THE 4'X8' "ALL TRAFFIC" SIGNS SHALL BE THE SAME SHAPE.
- ⑦ THE NUMBER OF ARROWS ON THESE SIGNS SHALL MATCH THE NUMBER OF LANES OPEN TO TRAFFIC.


## SYMBOLS

- |                                                                                       |                                                                      |
|---------------------------------------------------------------------------------------|----------------------------------------------------------------------|
|  | DIRECTION OF TRAFFIC                                                 |
|  | WORK AREA                                                            |
|  | SIGN ON PORTABLE OR PERMANENT SUPPORT                                |
|  | TYPE II BARRICADE OR DRUM WITH MONO-DIRECTIONAL STEADY BURNING LIGHT |
|  | TEMPORARY CONCRETE BARRIER WALL                                      |
|  | IMPACT ATTENUATOR                                                    |
|  |                                                                      |
- W24-1-48
- (7)

ALL DIMENSIONS ARE IN INCHES (MILLIMETERS)  
UNLESS OTHERWISE SHOWN

|                                            |                     |                     |                     |                                                   |                                                                  |                         |              |                                                 |         |        |              |           |
|--------------------------------------------|---------------------|---------------------|---------------------|---------------------------------------------------|------------------------------------------------------------------|-------------------------|--------------|-------------------------------------------------|---------|--------|--------------|-----------|
| FILE NAME =                                | USER NAME = footemj | DESIGNED - DWS      | REVISED - JAF 02-06 | STATE OF ILLINOIS<br>DEPARTMENT OF TRANSPORTATION | TRAFFIC CONTROL DETAILS FOR<br>FREEWAY SINGLE & MULTI-LANE WEAVE |                         |              | F.A.I. RT.                                      | SECTION | COUNTY | TOTAL SHEETS | SHEET NO. |
| c:\pw\work\p\dot\footemj\00108315\td09.dgn | DRAWN -             | REVISED - SPB 01-07 | REVISED - SPB 12-09 |                                                   | 90/94                                                            | 2012-0521               | COOK         | 165                                             | 111     |        |              |           |
| PLOT SCALE = 50.000' / in.                 | CHECKED -           | REVISED - MD 06-13  |                     |                                                   | TC-09                                                            |                         |              | CONTRACT NO. 60T93                              |         |        |              |           |
| PLOT DATE = 7/1/2013                       | DATE = 02-87        |                     |                     |                                                   | SCALE: NONE                                                      | SHEET NO. 1 OF 1 SHEETS | STA. TO STA. | FED. ROAD DIST. NO. 1 ILLINOIS FED. AID PROJECT |         |        |              |           |

PARTIAL RAMP CLOSURE DETAILS

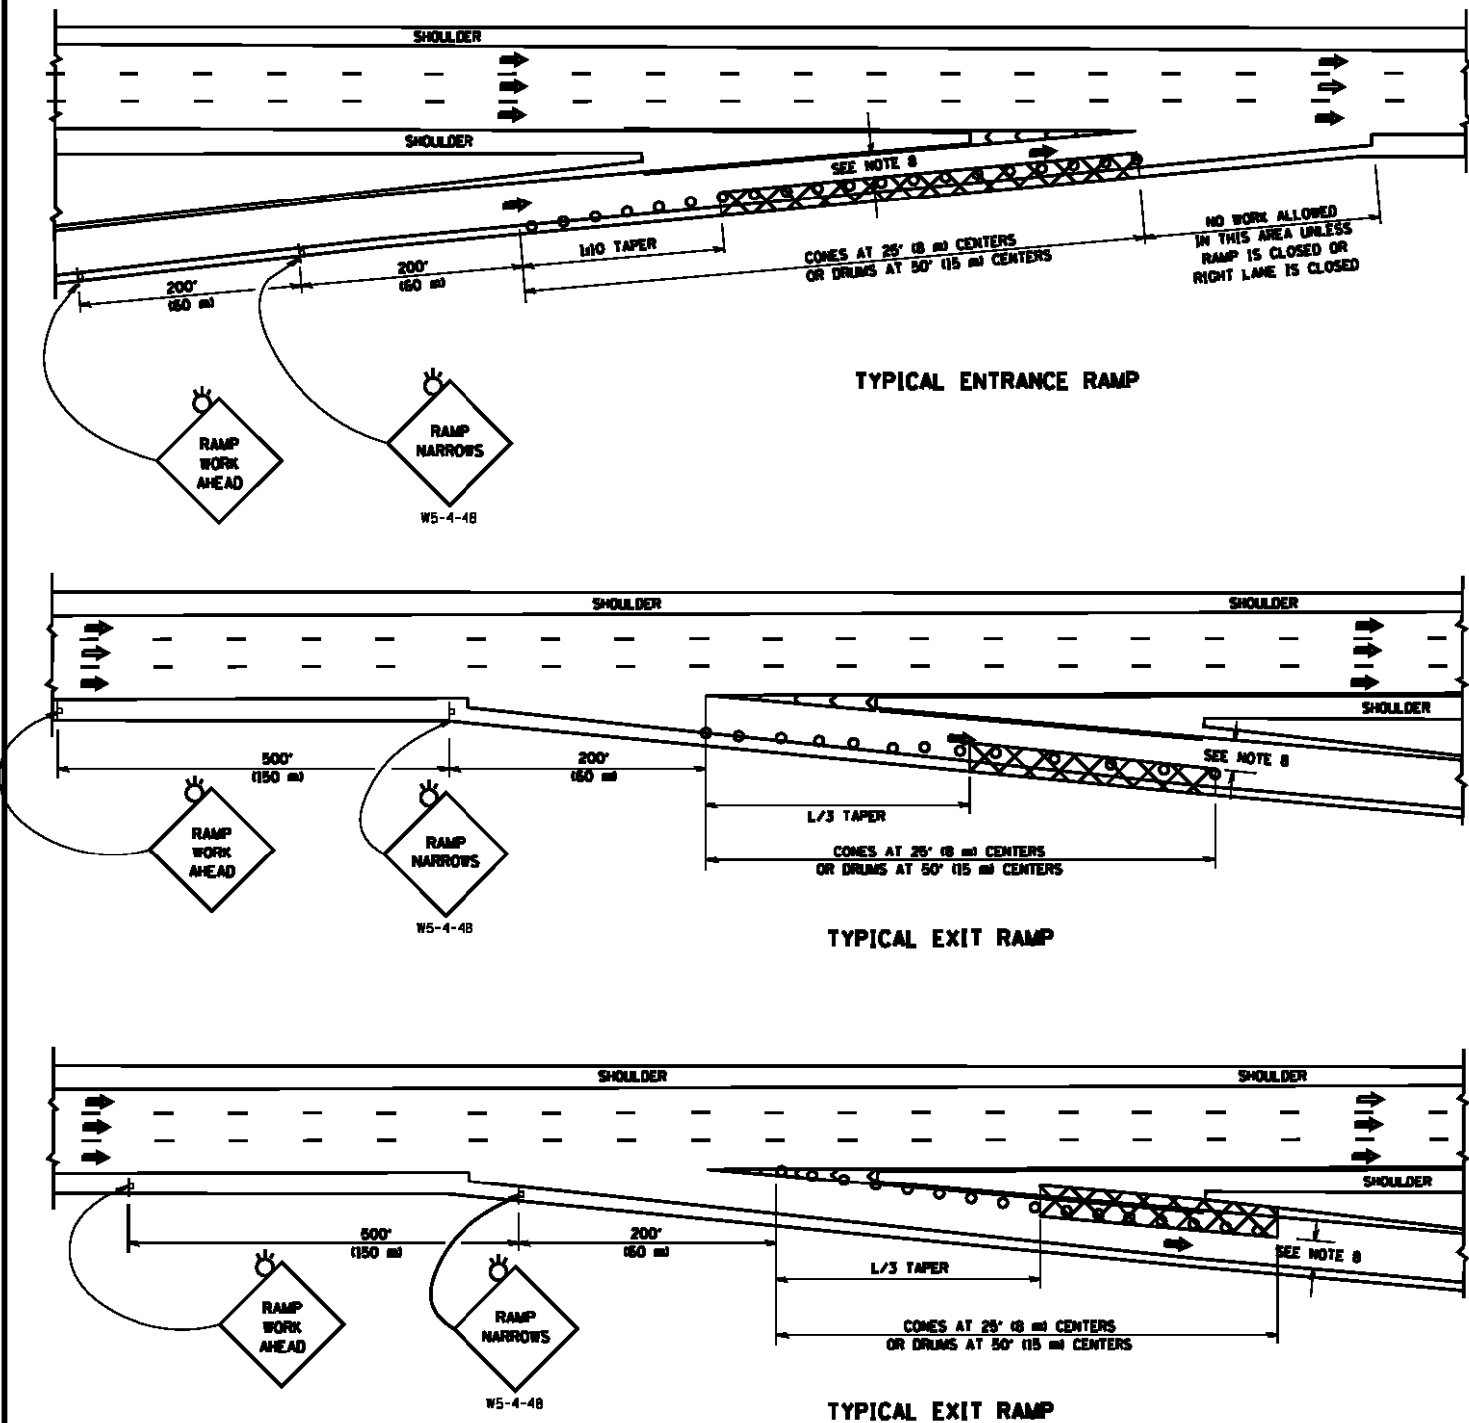


SYMBOLS

- ACTIVE WORK AREA
- SIGN ON PORTABLE OR PERMANENT SUPPORT
- FLAGGER WITH CONTROL SIGN
- TYPE II BARRICADE OR DRUM WITH STEADY BURN MONO-DIRECTIONAL LIGHT
- CONE, DRUM OR BARRICADE
- IMPACT ATTENUATOR OF TYPE AND TEST LEVEL SPECIFIED

GENERAL NOTES

1. THE "L" DISTANCE EQUALS:  
SPEED LIMIT FORMULAS  
45 mph (80 km/h) OR GREATER:  $L = 0.0001S^3$  METRIC  
45 mph (80 km/h) OR GREATER:  $L = 0.0001S^3$  ENGLISH  
S = WIDTH OF OFFSET IN FEET (METERS)  
S = NORMAL POSTED SPEED MPH (KM/H)
2. PLASTIC DRUMS WITH HIGH PERFORMANCE REFLECTIVE SHEETING AND STEADY BURNING LIGHTS ARE REQUIRED FOR ALL NIGHTTIME CLOSURES.
3. ALL SIGNS SHALL BE POST MOUNTED IF THE CLOSURE TIME EXCEEDS FOUR DAYS.
4. FLASHING LIGHTS SHALL BE USED DURING THE HOURS OF DARKNESS AND SHALL BE INSTALLED ABOVE THE FIRST TWO SETS OF SIGNS.

SHOULDER CLOSURE DETAILS

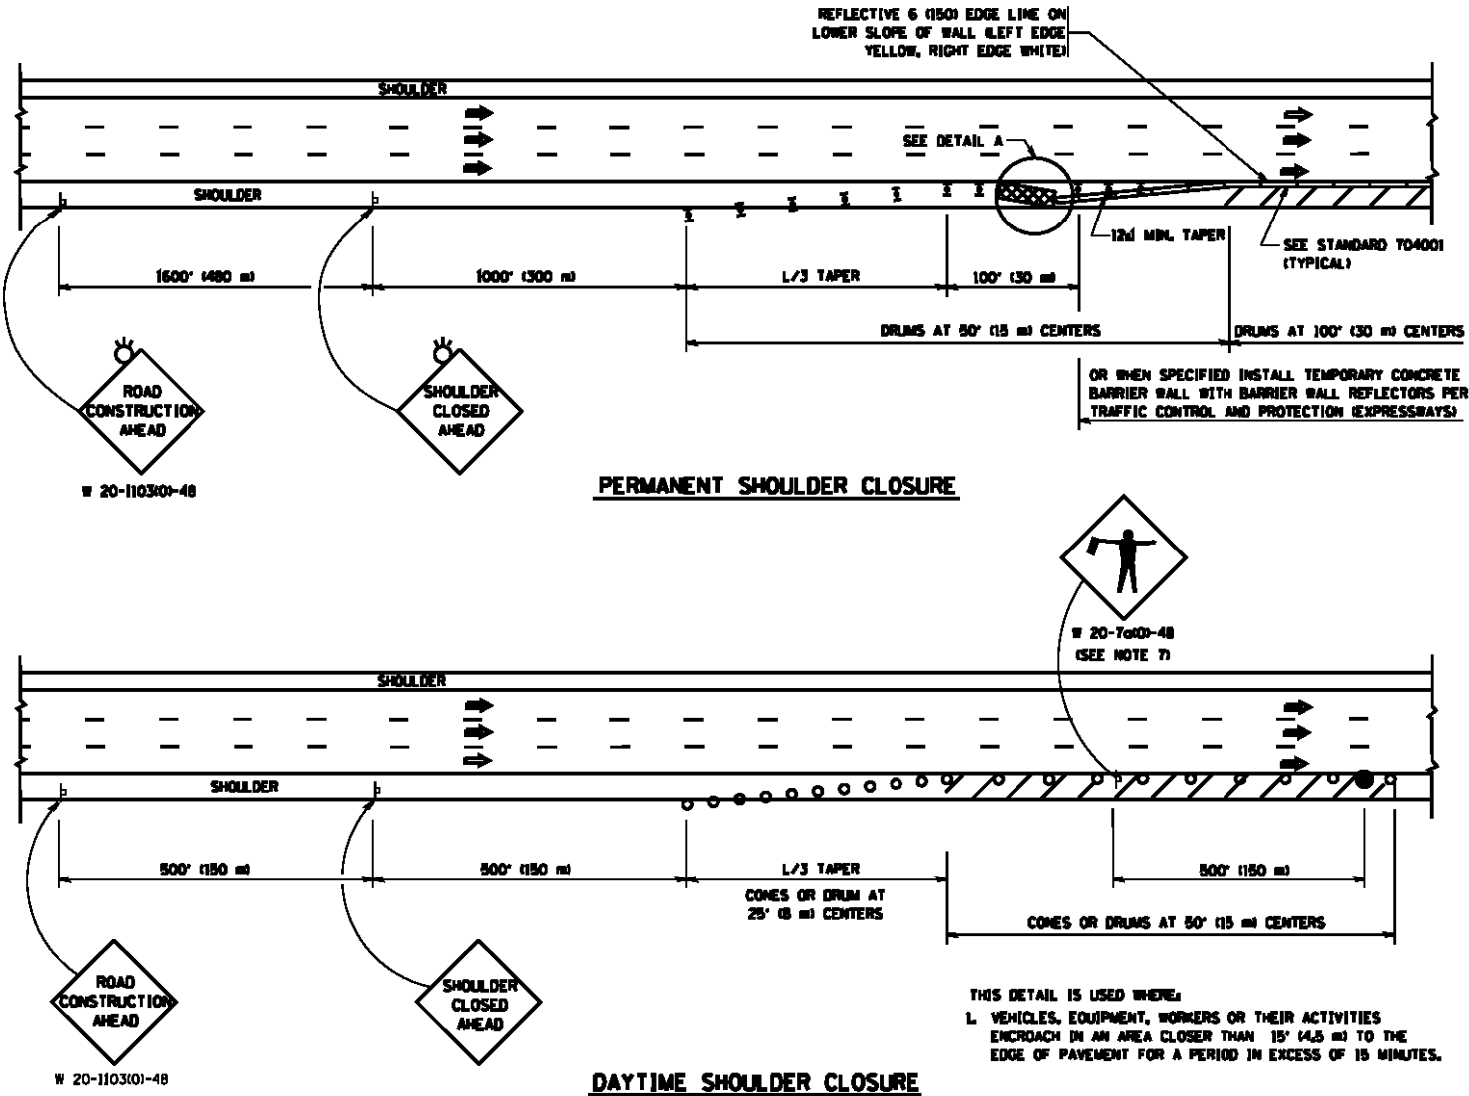

ARRAY DESIGN PER MANUFACTURER TO BE NCHRP 350/MASH COMPLIANT.

DETAIL "A"  
IMPACT ATTENUATOR, TEMPORARY  
(SEE NOTE 5)


5. THE IMPACT ATTENUATOR, TEMPORARY IS NOT REQUIRED WHEN THE TEMPORARY CONCRETE BARRIER WALL IS PROTECTED BY OR IS TIED INTO THE EXISTING GUARDRAIL. IF OFFSET IS LESS THAN 5 FEET USE NARROW USE TYPE DEVICE TO MEET NCHRP350/MASH.
6. AUTHORIZATION FROM THE DISTRICT'S BUREAU OF TRAFFIC IS REQUIRED FOR ALL FREEWAY CLOSURES.
7. THE FLAGGER AND FLAGGER SIGN ARE REQUIRED AT THE ABOVE WORK SITES WHEN:  
a. FOUR OR MORE WORK VEHICLES ENTER THE TRAFFIC LANES IN A ONE HOUR PERIOD.  
d. THE WORK ACTIVITY REQUIRES FREQUENT ENCRDACHMENT INTO THE LANE OPEN TO TRAFFIC.  
THE FLAGGER SHALL BE STATIONED APPROXIMATELY 100' (30 m) TO 200' (60 m) IN ADVANCE OF THE WORKERS.
8. 12" MIN. WIDTH TANGENT SECTION  
18" MIN. WIDTH CURVE SECTION.

ALL DIMENSIONS ARE IN INCHES (MILLIMETERS) UNLESS OTHERWISE SHOWN.


|                                            |                         |                |                        |                                                   |                                                                                    |  |  |                    |           |        |              |           |
|--------------------------------------------|-------------------------|----------------|------------------------|---------------------------------------------------|------------------------------------------------------------------------------------|--|--|--------------------|-----------|--------|--------------|-----------|
| FILE NAME =                                | USER NAME = leysa       | DESIGNED -     | REVISED - J.A.F. 12-06 | STATE OF ILLINOIS<br>DEPARTMENT OF TRANSPORTATION | TRAFFIC CONTROL DETAILS FOR FREEWAY<br>SHOULDER CLOSURES AND PARTIAL RAMP CLOSURES |  |  | F.A.1-<br>RTE.     | SECTION   | COUNTY | TOTAL SHEETS | SHEET NO. |
| ed:\pa_work\panda\leysa\cd8186315\cd17.dgn |                         | DRAWN - D.W.S. | REVISED - S.P.B. 01-07 |                                                   |                                                                                    |  |  | 90/94              | 2012-0521 | COOK   | 165          | 112       |
|                                            | PLOT SCALE = 1/8"=1'-0" | CHECKED -      | REVISED - S.P.B. 12-09 |                                                   | SCALE: NONE                                                                        |  |  | TC-17              |           |        |              |           |
|                                            | PLOT DATE = 4/17/2014   | DATE - 11-96   | REVISED - M.D. 06-13   |                                                   | SHEET NO. 1 OF 1 SHEETS                                                            |  |  | CONTRACT NO. 60T93 |           |        |              |           |

SIGNING FOR FLAGGING OPERATIONS AT WORK ZONE OPENINGS

WORK ZONE EXIT OPENING

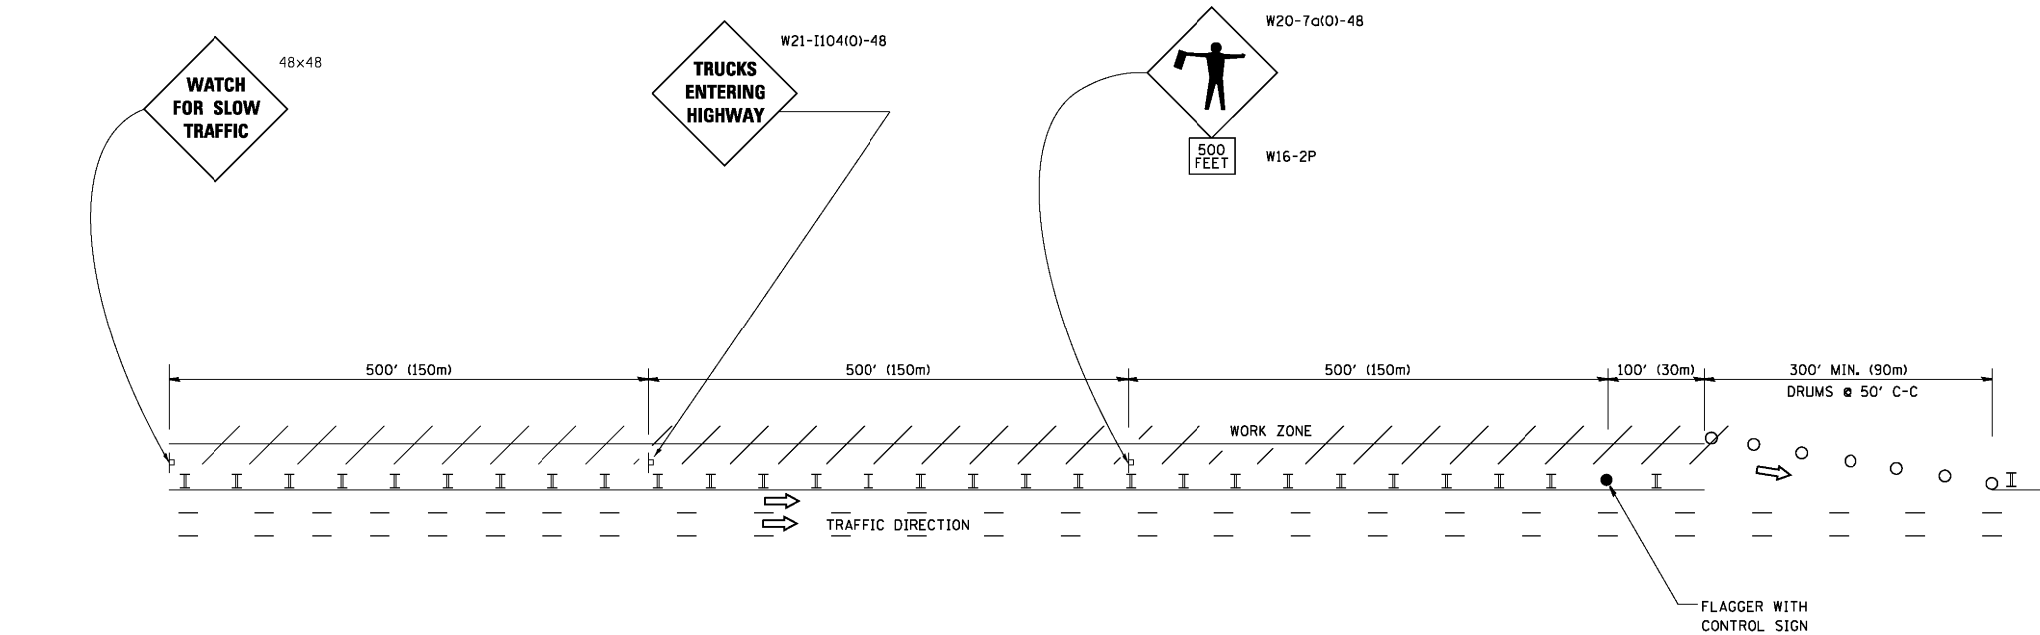

WORK ZONE ENTRY OPENING

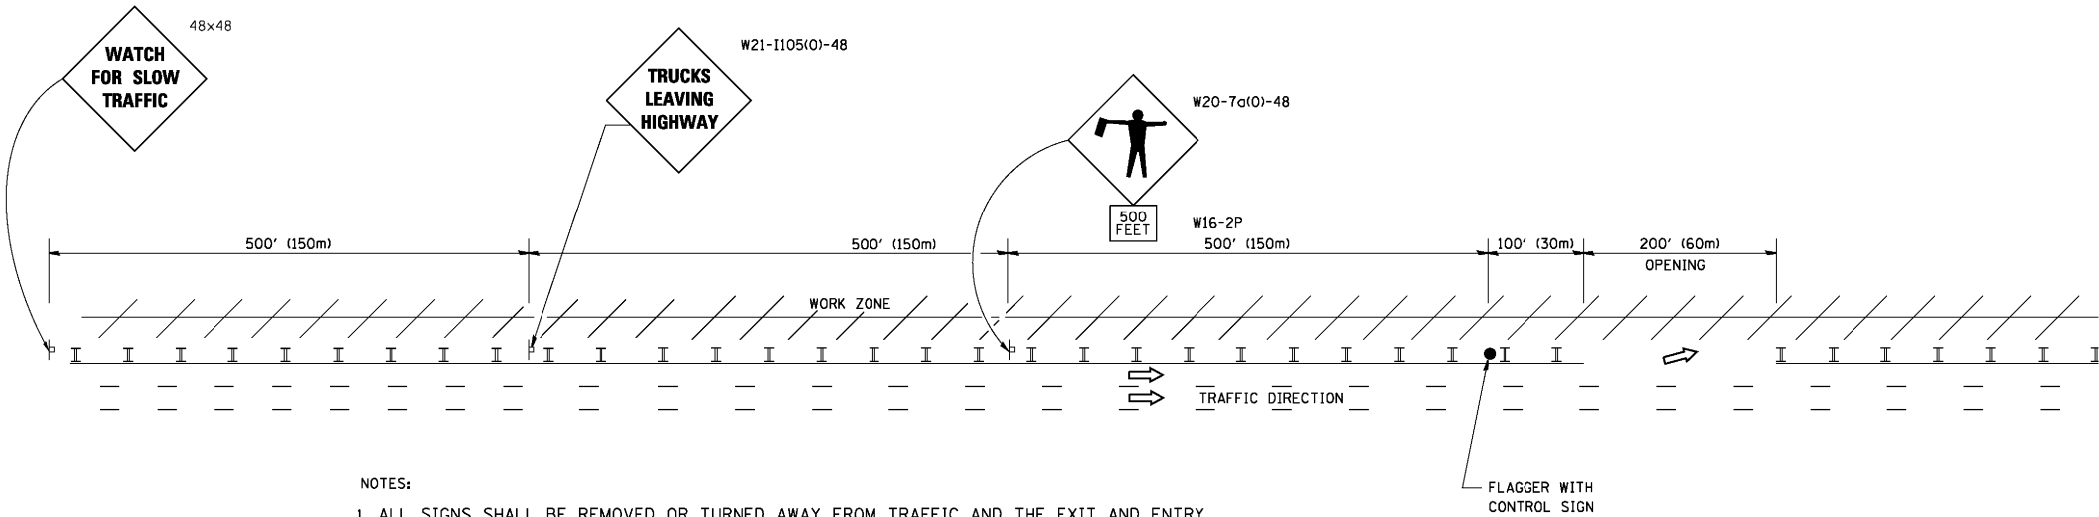


NOTES:

1. ALL SIGNS SHALL BE REMOVED OR TURNED AWAY FROM TRAFFIC AND THE EXIT AND ENTRY OPENINGS SHALL BE CLOSED WHEN THE FLAGGING OPERATION CEASES. NON OPERATING EQUIPMENT SHALL COMPLY WITH ARTICLE 701.11
2. WORK ZONE OPENINGS SHALL BE A MINIMUM OF ONE HALF MILE APART AND A MINIMUM OF ONE QUARTER MILE FROM ALL ENTRANCE AND EXIT RAMP.
3. EXITING THE WORK ZONE AT ANY PLACE OTHER THAN AT A WORK ZONE EXIT OPENING WILL BE PROHIBITED.
4. ALL VEHICLES SHALL ENTER THE WORK ZONE AT ENTRY OPENINGS, USING THEIR TURN SIGNALS TO WARN MOTORISTS
5. FLAGGERS SHALL NOT STOP TRAFFIC OR DIRECT TRAFFIC INTO AN ADJACENT LANE.

ALL DIMENSIONS ARE IN INCHES (MILLIMETERS)  
UNLESS OTHERWISE SHOWN


|                                              |                     |                             |                        |                                                   |                                                                                                     |             |                         |                    |           |                                                     |              |           |
|----------------------------------------------|---------------------|-----------------------------|------------------------|---------------------------------------------------|-----------------------------------------------------------------------------------------------------|-------------|-------------------------|--------------------|-----------|-----------------------------------------------------|--------------|-----------|
| FILE NAME =                                  | USER NAME = footemj | DESIGNED -                  | REVISED - J.A.F. 02-06 | STATE OF ILLINOIS<br>DEPARTMENT OF TRANSPORTATION | FREEWAY/EXPRESSWAY SIGNING FOR FLAGGING OPERATIONS<br>AT WORK ZONE OPENINGS ON FREEWAYS/EXPRESSWAYS |             |                         | F.A.I. RTE.        | SECTION   | COUNTY                                              | TOTAL SHEETS | SHEET NO. |
| c:\pw_work\pw\dot\footemj\ad0108315\sc18.dgn |                     | DRAWN -                     | REVISED - S.P.B. 01-07 |                                                   |                                                                                                     |             |                         | 90/94              | 2012-0521 | COOK                                                | 165          | 113       |
|                                              |                     | PLOT SCALE = 50.000 ' / in. | CHECKED - S.P.B. 12-09 |                                                   | TC-18                                                                                               |             |                         | CONTRACT NO. 60T93 |           |                                                     |              |           |
|                                              |                     | PLOT DATE = 7/8/2013        | DATE -                 |                                                   | REVISED - M.D. 06-13                                                                                | SCALE: NONE | SHEET NO. 1 OF 1 SHEETS | STA.               | TO STA.   | FED. ROAD DIST. NO. 1   ILLINOIS   FED. AID PROJECT |              |           |

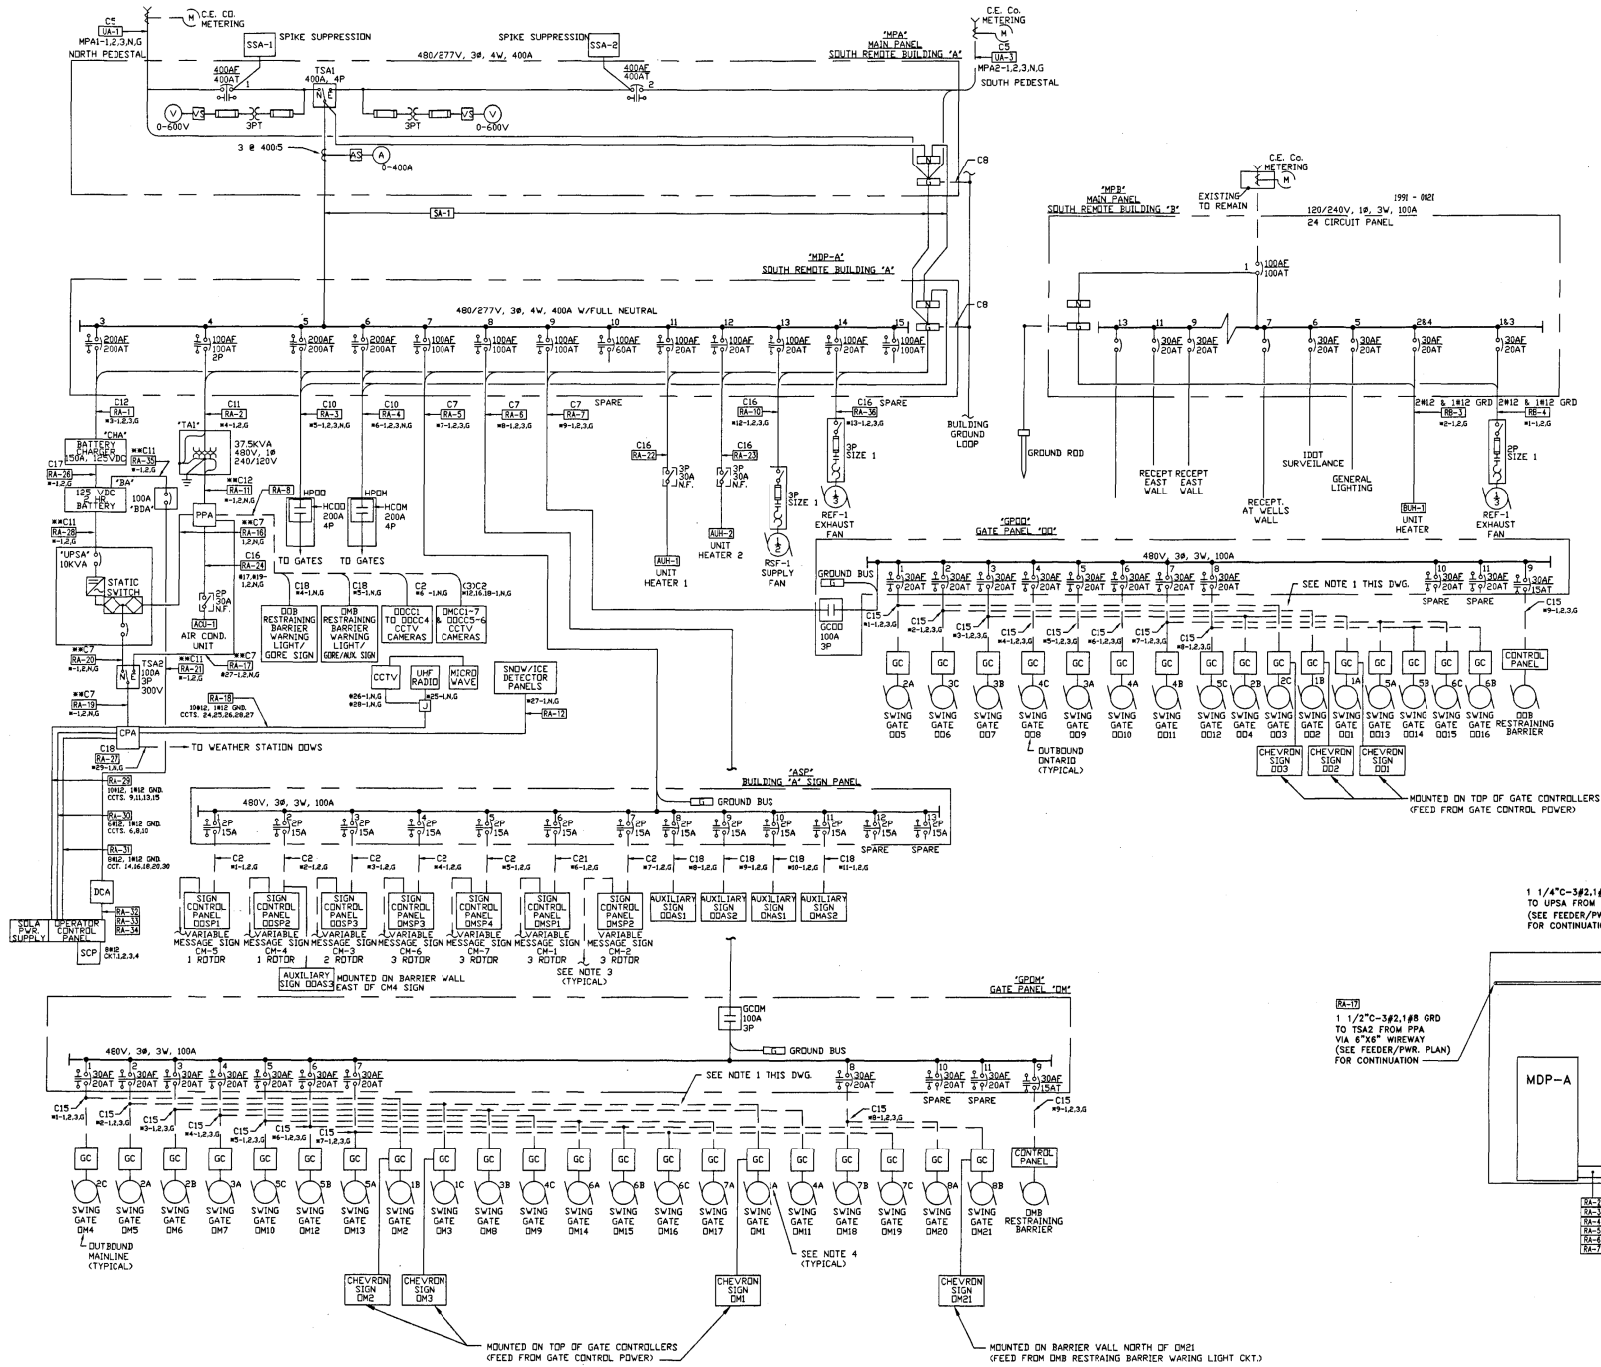

- NOTES:
- 1) POWER LINES TO INDIVIDUAL GATE CONTROLS TO BE PULLED THROUGH EXISTING 4" CONDUIT.
  - 2) \* INDICATES PANEL PREFIX.
  - 3) CIRCUIT FROM ROADWAY LIGHTING CONTROL.
  - 4) NUMBER SHOWN ADJACENT TO SWING GATE MOTOR IDENTIFIES CIRCUIT NUMBER OF THREE PHASE BREAKER IN RESPECTIVE GATE HEATER PANEL. LETTER INDICATES PHASE TO BE USED TO FEED THE 277V GATE HEATER. EXAMPLE: SWING GATE DM1 IS FED FROM PANEL HPOM, CIRCUIT NUMBER ONE, PHASE A (SWING GATES DM2 & DM3 ARE FED FROM PHASE B AND PHASE C OF THE SAME CIRCUIT). SEE TYPICAL WIRING DIAGRAM ON DWG. E-89.

| CABLE SCHEDULE |                               |         |
|----------------|-------------------------------|---------|
| TAG            | NO. & WIRE SIZE               | REMARKS |
| C1             | 4#4/0, 1#6 GND.               |         |
| C2             | 2#6, 1#10 GND.                |         |
| C3             | 3#4, 1#6 GND.                 |         |
| C4             | 2#1/0, 1#4 GND.               |         |
| C5             | 4#500CM, 1#1/0 GND.           |         |
| C6             | 3#6, 1#10 GND.                |         |
| C7             | 3#2, 1#8 GND. **2#2, 1#8GND.  |         |
| C8             | 1#4/0 GROUND WIRE             |         |
| C9             | 3#6, 1#10 GND.                |         |
| C10            | 4#3/0 1#6 GND.                |         |
| C11            | 2#2, 1#8 GND. **2#1, 1#8GND.  |         |
| C12            | 3#2/0 1#4 GND. **3#2, 1#4GND. |         |
| C13            | 2 SETS OF 4#250CM, 1#2 GND/EA |         |
| C14            | 3#1, 1#6 GND.                 |         |
| C15            | 2#10, 1#10 GND.               |         |
| C16            | 3#12, 1#12 GND.               |         |
| C17            | 2#4/0, 1#4 GND.               |         |
| C18            | 2#10, 1#10 GND.               |         |
| C19            | 2#8, 1#10 GND.                |         |
| C20            | 4#10, 1#10 GND.               |         |
| C21            | 2/C #4, 1#10 GND.             |         |

| CHANGEABLE MESSAGE SIGN AUXILIARY FEEDER SCHEDULE |                               |
|---------------------------------------------------|-------------------------------|
| CM-1                                              | FEED FROM IDOT PWR CENTER "Y" |
| CM-2                                              | FEED FROM IDOT PWR CENTER "Y" |
| CM-3                                              | FEED FROM IDOT PWR CENTER "S" |
| CM-4                                              | FEED FROM IDOT PWR CENTER "S" |
| CM-5                                              | FEED FROM IDOT PWR CENTER "S" |
| CM-6                                              | FEED FROM IDOT PWR CENTER "S" |
| CM-7                                              | FEED FROM IDOT PWR CENTER "N" |

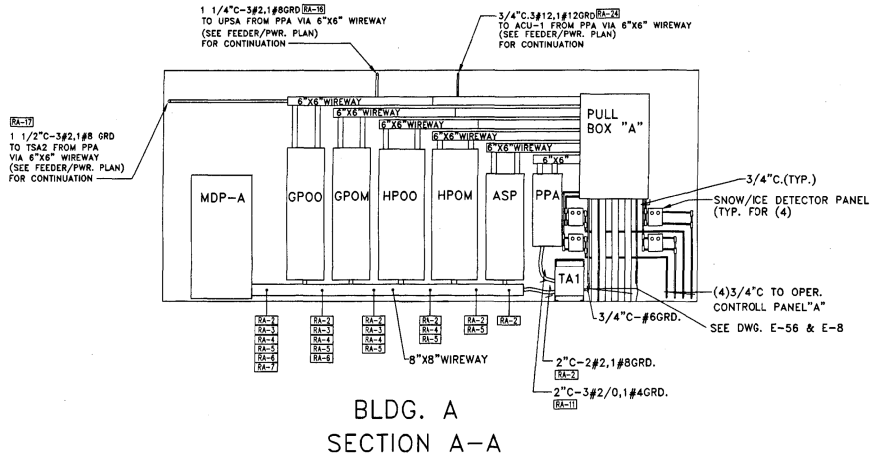

- NOTES:
1. THE ABOVE DRAWINGS REPRESENT AS LET DESIGN TO AID CONTRACTOR IN ASCERTAINING EXISTING CONDITIONS.
  2. CONTRACTOR SHALL CONTACT IDOT D1 TO REQUEST THE MOST UP TO DATE RECORD DRAWINGS AVAILABLE AT THE TIME OF LETTING.

**FOR INFORMATION ONLY**

J:\293\Task-2\CON\CADD Sheet\514.D160T93-sh1-details055.dgn

**SINGH**  
SINGH - ASSOCIATES INC.  
CONSULTING ENGINEERS

USER NAME = mgarvido  
FILE NAME = 114.D160T93-sh1-details055  
PLOT SCALE = 2.000000:1.000000  
PLOT DATE = 06-MAY-2015 15:27

DESIGNED - DJ/AG  
DRAWN - DS/AS  
CHECKED - 1Y  
DATE - 5/6/2015


REVISED -  
REVISED -  
REVISED -  
REVISED -

STATE OF ILLINOIS  
DEPARTMENT OF TRANSPORTATION


REMOTE BUILDING A SINGLE LINE DIAGRAM

SCALE: NTS SHEET OF SHEETS STA. TO STA.


| F.A.I. RTE.               | SECTION   | COUNTY | TOTAL SHEETS | SHEET NO. |
|---------------------------|-----------|--------|--------------|-----------|
| 90/94                     | 2012-0521 | COOK   | 165          | 114       |
| CONTRACT NO. 60T93        |           |        |              |           |
| ILLINOIS FED. AID PROJECT |           |        |              |           |

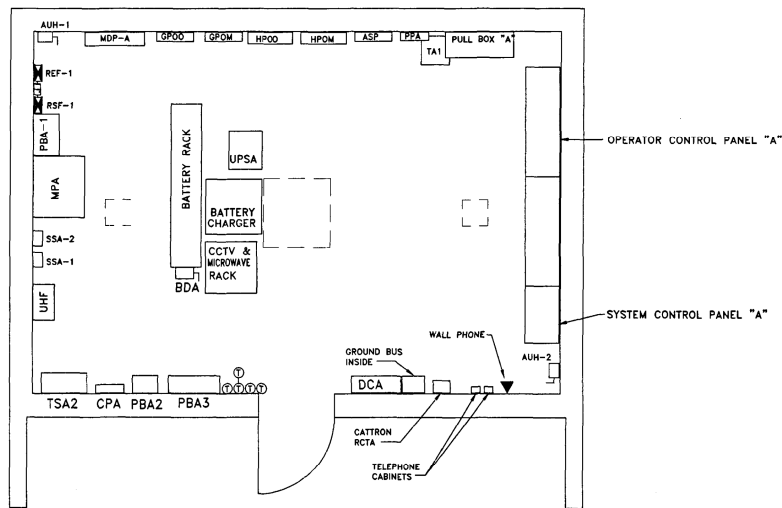

BLDG. A  
EQUIPMENT LAYOUT

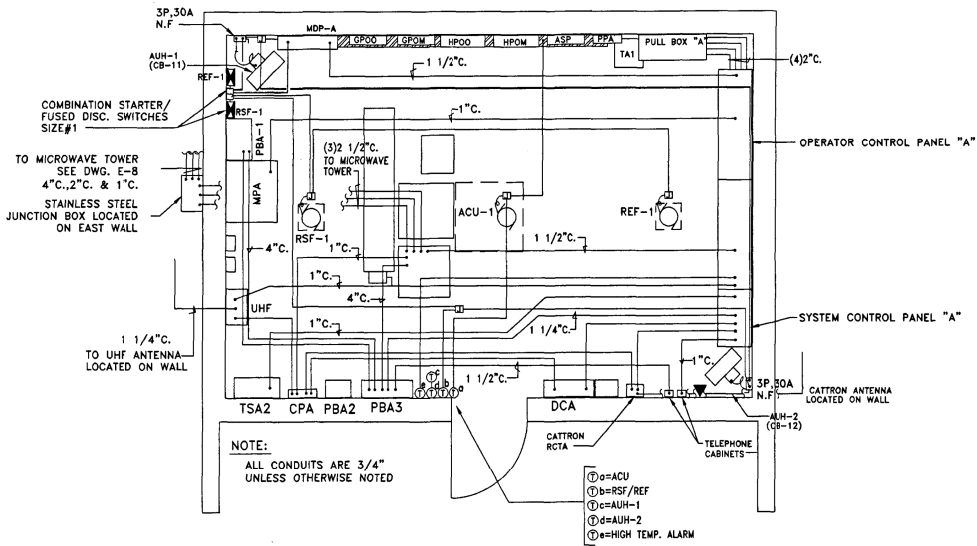

BLDG. A  
COMMUNICATIONS  
AND HVAC

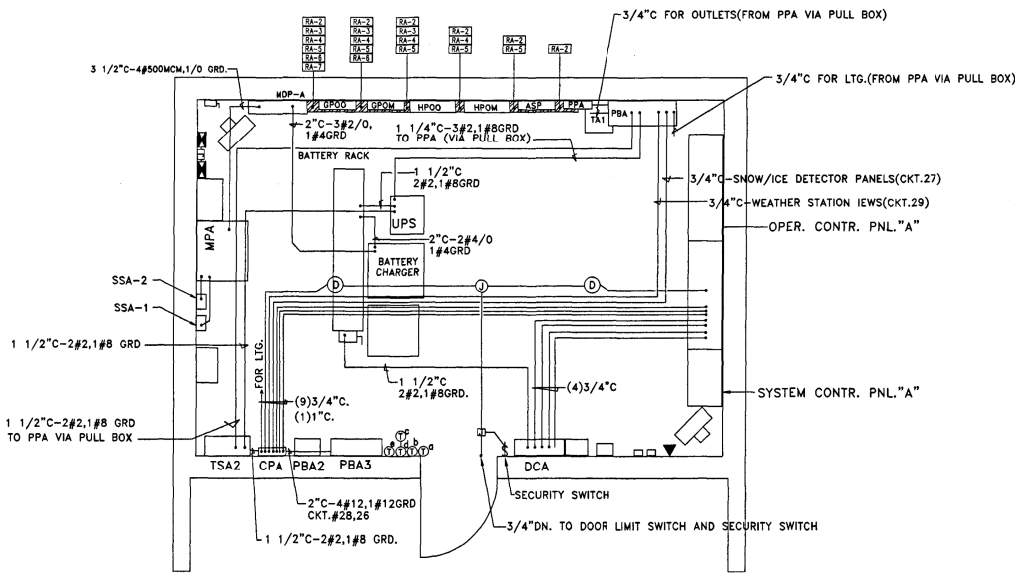

BLDG. A  
FEEDERS AND POWER

NOTES:

1. THE ABOVE DRAWINGS REPRESENT AS LET DESIGN TO AID CONTRACTOR IN ASCERTAINING EXISTING CONDITIONS.
2. CONTRACTOR SHALL CONTACT IDOT D1 TO REQUEST THE MOST UP TO DATE RECORD DRAWINGS AVAILABLE AT THE TIME OF LETTING.

FOR INFORMATION ONLY

J:\2013\Task-2\CON\CADD\_Sheet\115\_D160T93-shr-details056.dgn

**SINGH**  
SINGH - ASSOCIATES INC.  
CONSULTING ENGINEERS

|                                        |                  |           |
|----------------------------------------|------------------|-----------|
| USER NAME = mgarvda                    | DESIGNED - DJ/AG | REVISED - |
| FILE NAME = 115_D160T93-shr-details056 | DRAWN - DS/AS    | REVISED - |
| PLOT SCALE = 2.000000:1.000000         | CHECKED - 1Y     | REVISED - |
| PLOT DATE = 06-MAY-2015 15:28          | DATE - 5/6/2015  | REVISED - |


STATE OF ILLINOIS  
DEPARTMENT OF TRANSPORTATION

REMOTE BUILDING A EQUIPMENT LAYOUT

SCALE: NTS SHEET OF SHEETS STA. TO STA.

| F.A.I. RTE.               | SECTION   | COUNTY | TOTAL SHEETS | SHEET NO. |
|---------------------------|-----------|--------|--------------|-----------|
| 90/94                     | 2012-0521 | COOK   | 165          | 115       |
| CONTRACT NO. 60T93        |           |        |              |           |
| ILLINOIS FED. AID PROJECT |           |        |              |           |

J:\2013\Task-2\CON\CADD\_Sheet\516\_D160T93-sh1-details057.dgn

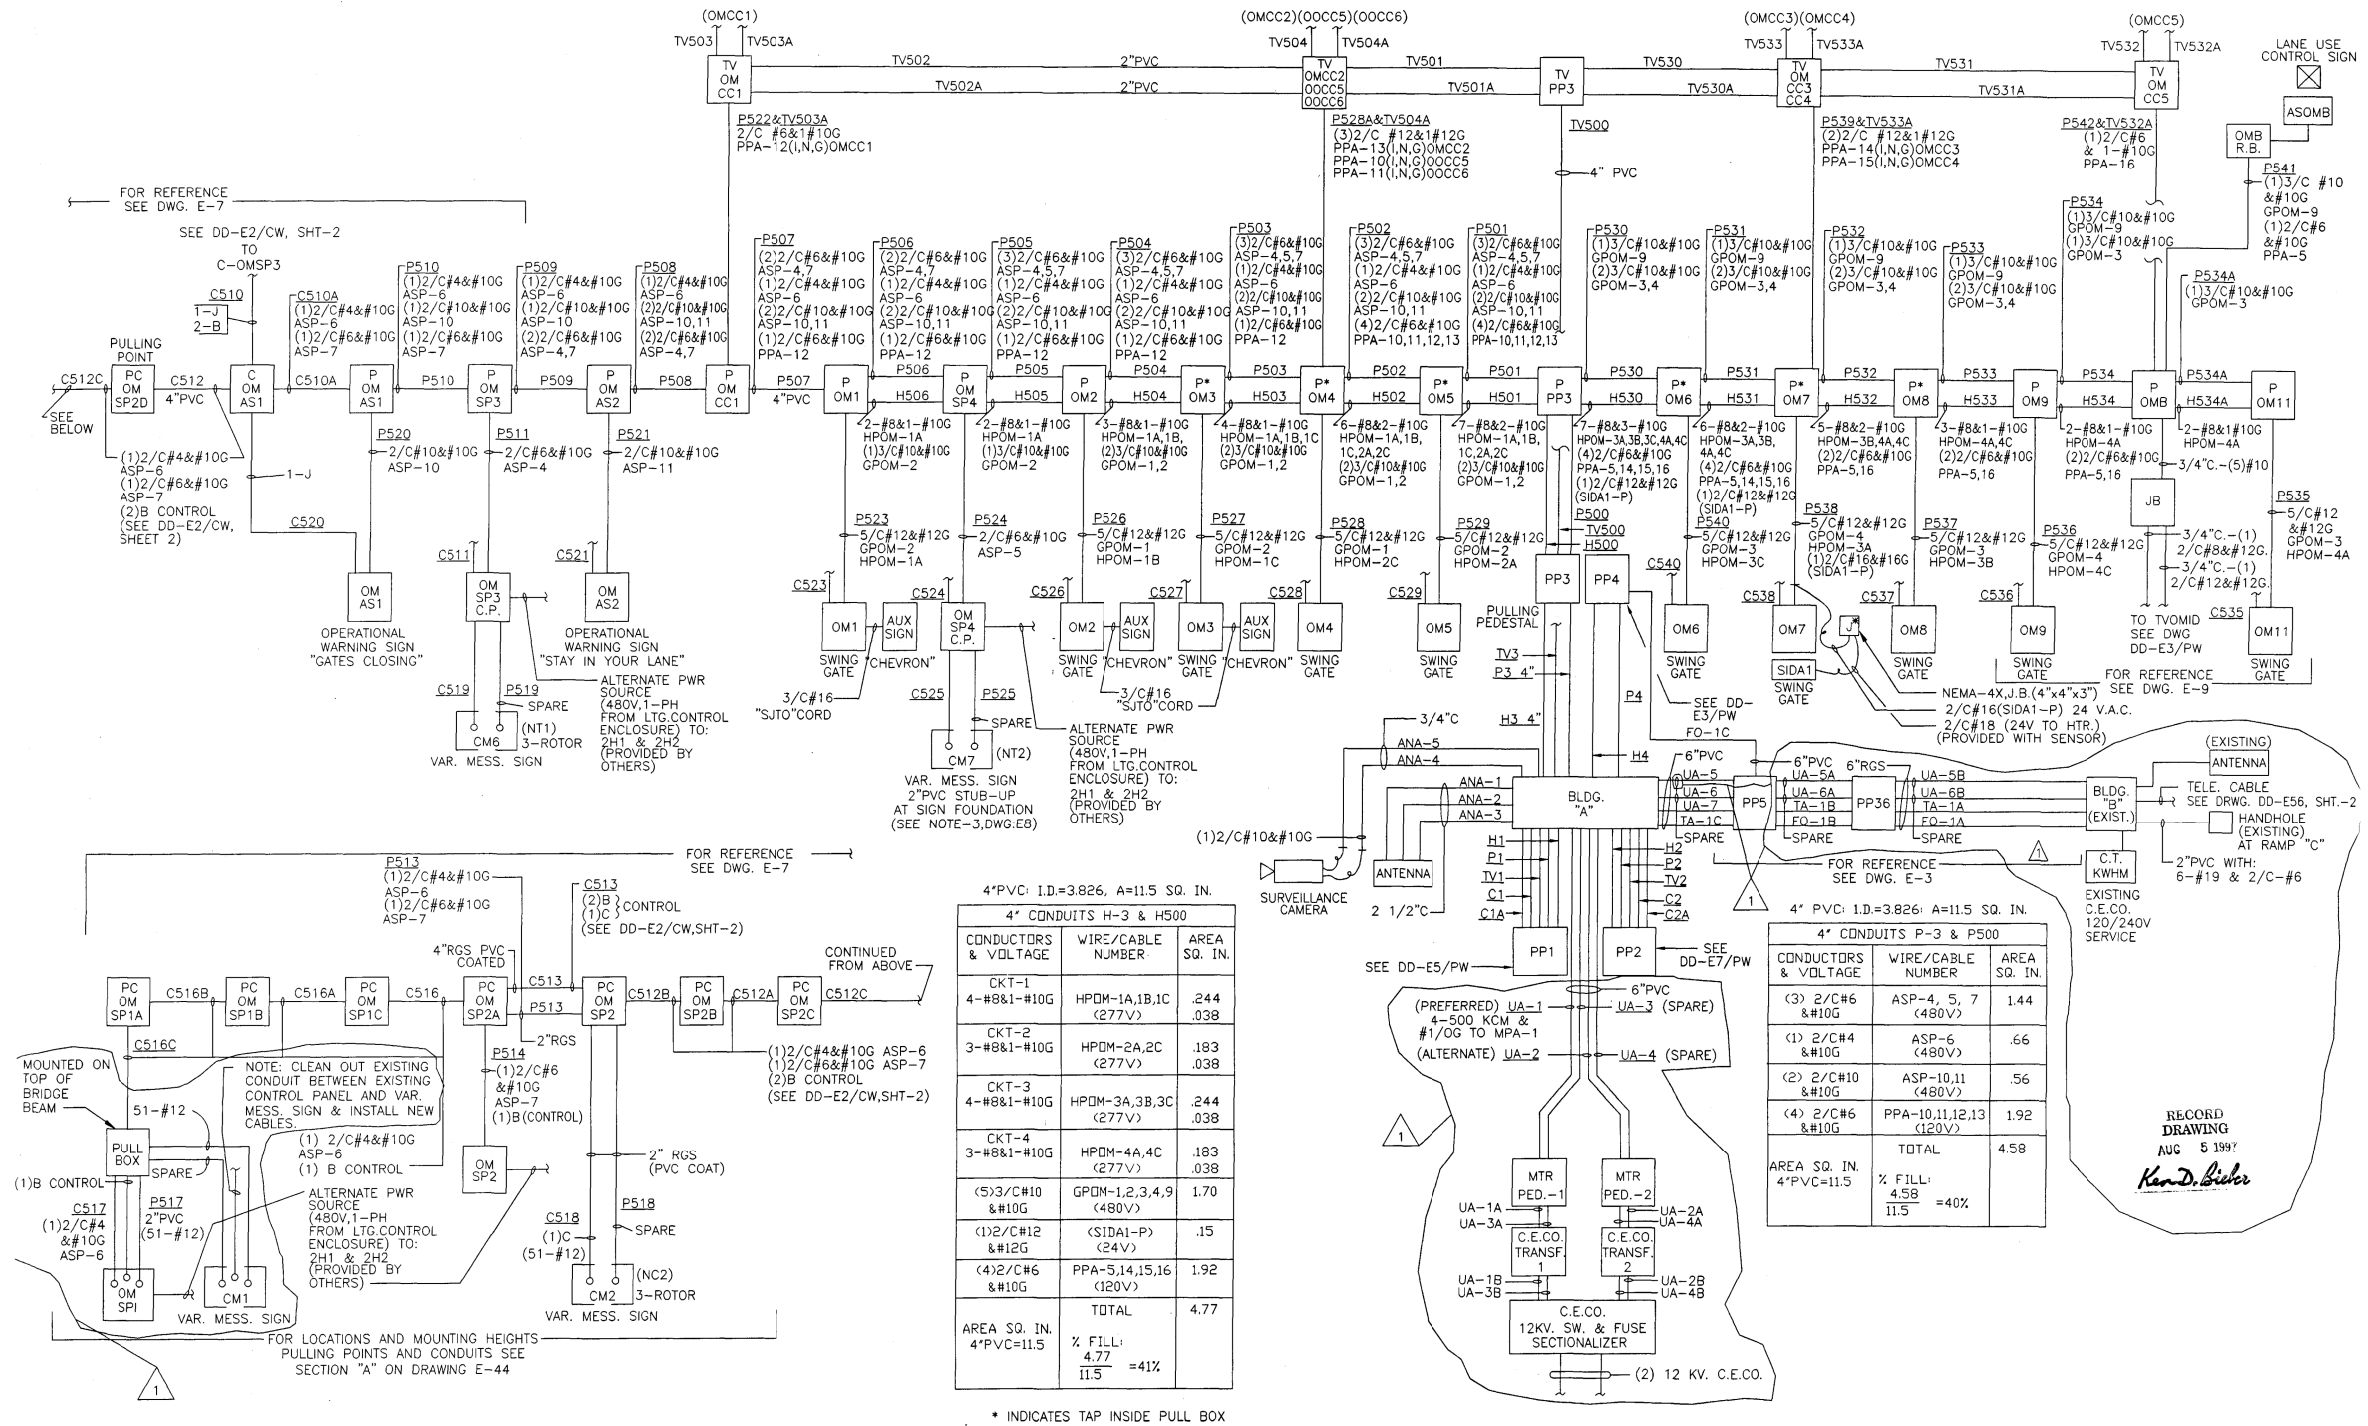

#### NOTES:

- THE ABOVE DRAWINGS REPRESENT AS LET DESIGN TO AID CONTRACTOR IN ASCERTAINING EXISTING CONDITIONS.
- CONTRACTOR SHALL CONTACT IDOT D1 TO REQUEST THE MOST UP TO DATE RECORD DRAWINGS AVAILABLE AT THE TIME OF LETTING.

**FOR INFORMATION ONLY**

**SINGH**  
SINGH - ASSOCIATES, INC.  
CONSULTING ENGINEERS

USER NAME = mgarvada  
FILE NAME = 116\_D160T93-sh1-details057  
PLOT SCALE = 2.000000:1.000000  
PLOT DATE = 06-MAY-2015 15:29

DESIGNED - DJ/AG  
DRAWN - DS/AS  
CHECKED - 1Y  
DATE - 5/6/2015

REVISED -  
REVISED -  
REVISED -  
REVISED -


STATE OF ILLINOIS  
DEPARTMENT OF TRANSPORTATION

REMOTE BUILDING A KENNEDY NORTHWEST BOUND  
POWER AND HEATER WIRING

SCALE: NTS SHEET OF SHEETS STA. TO STA.

|                           |           |        |              |           |
|---------------------------|-----------|--------|--------------|-----------|
| F.A.I. RTE.               | SECTION   | COUNTY | TOTAL SHEETS | SHEET NO. |
| 90/94                     | 2012-0521 | COOK   | 165          | 116       |
| CONTRACT NO. 60T93        |           |        |              |           |
| ILLINOIS FED. AID PROJECT |           |        |              |           |



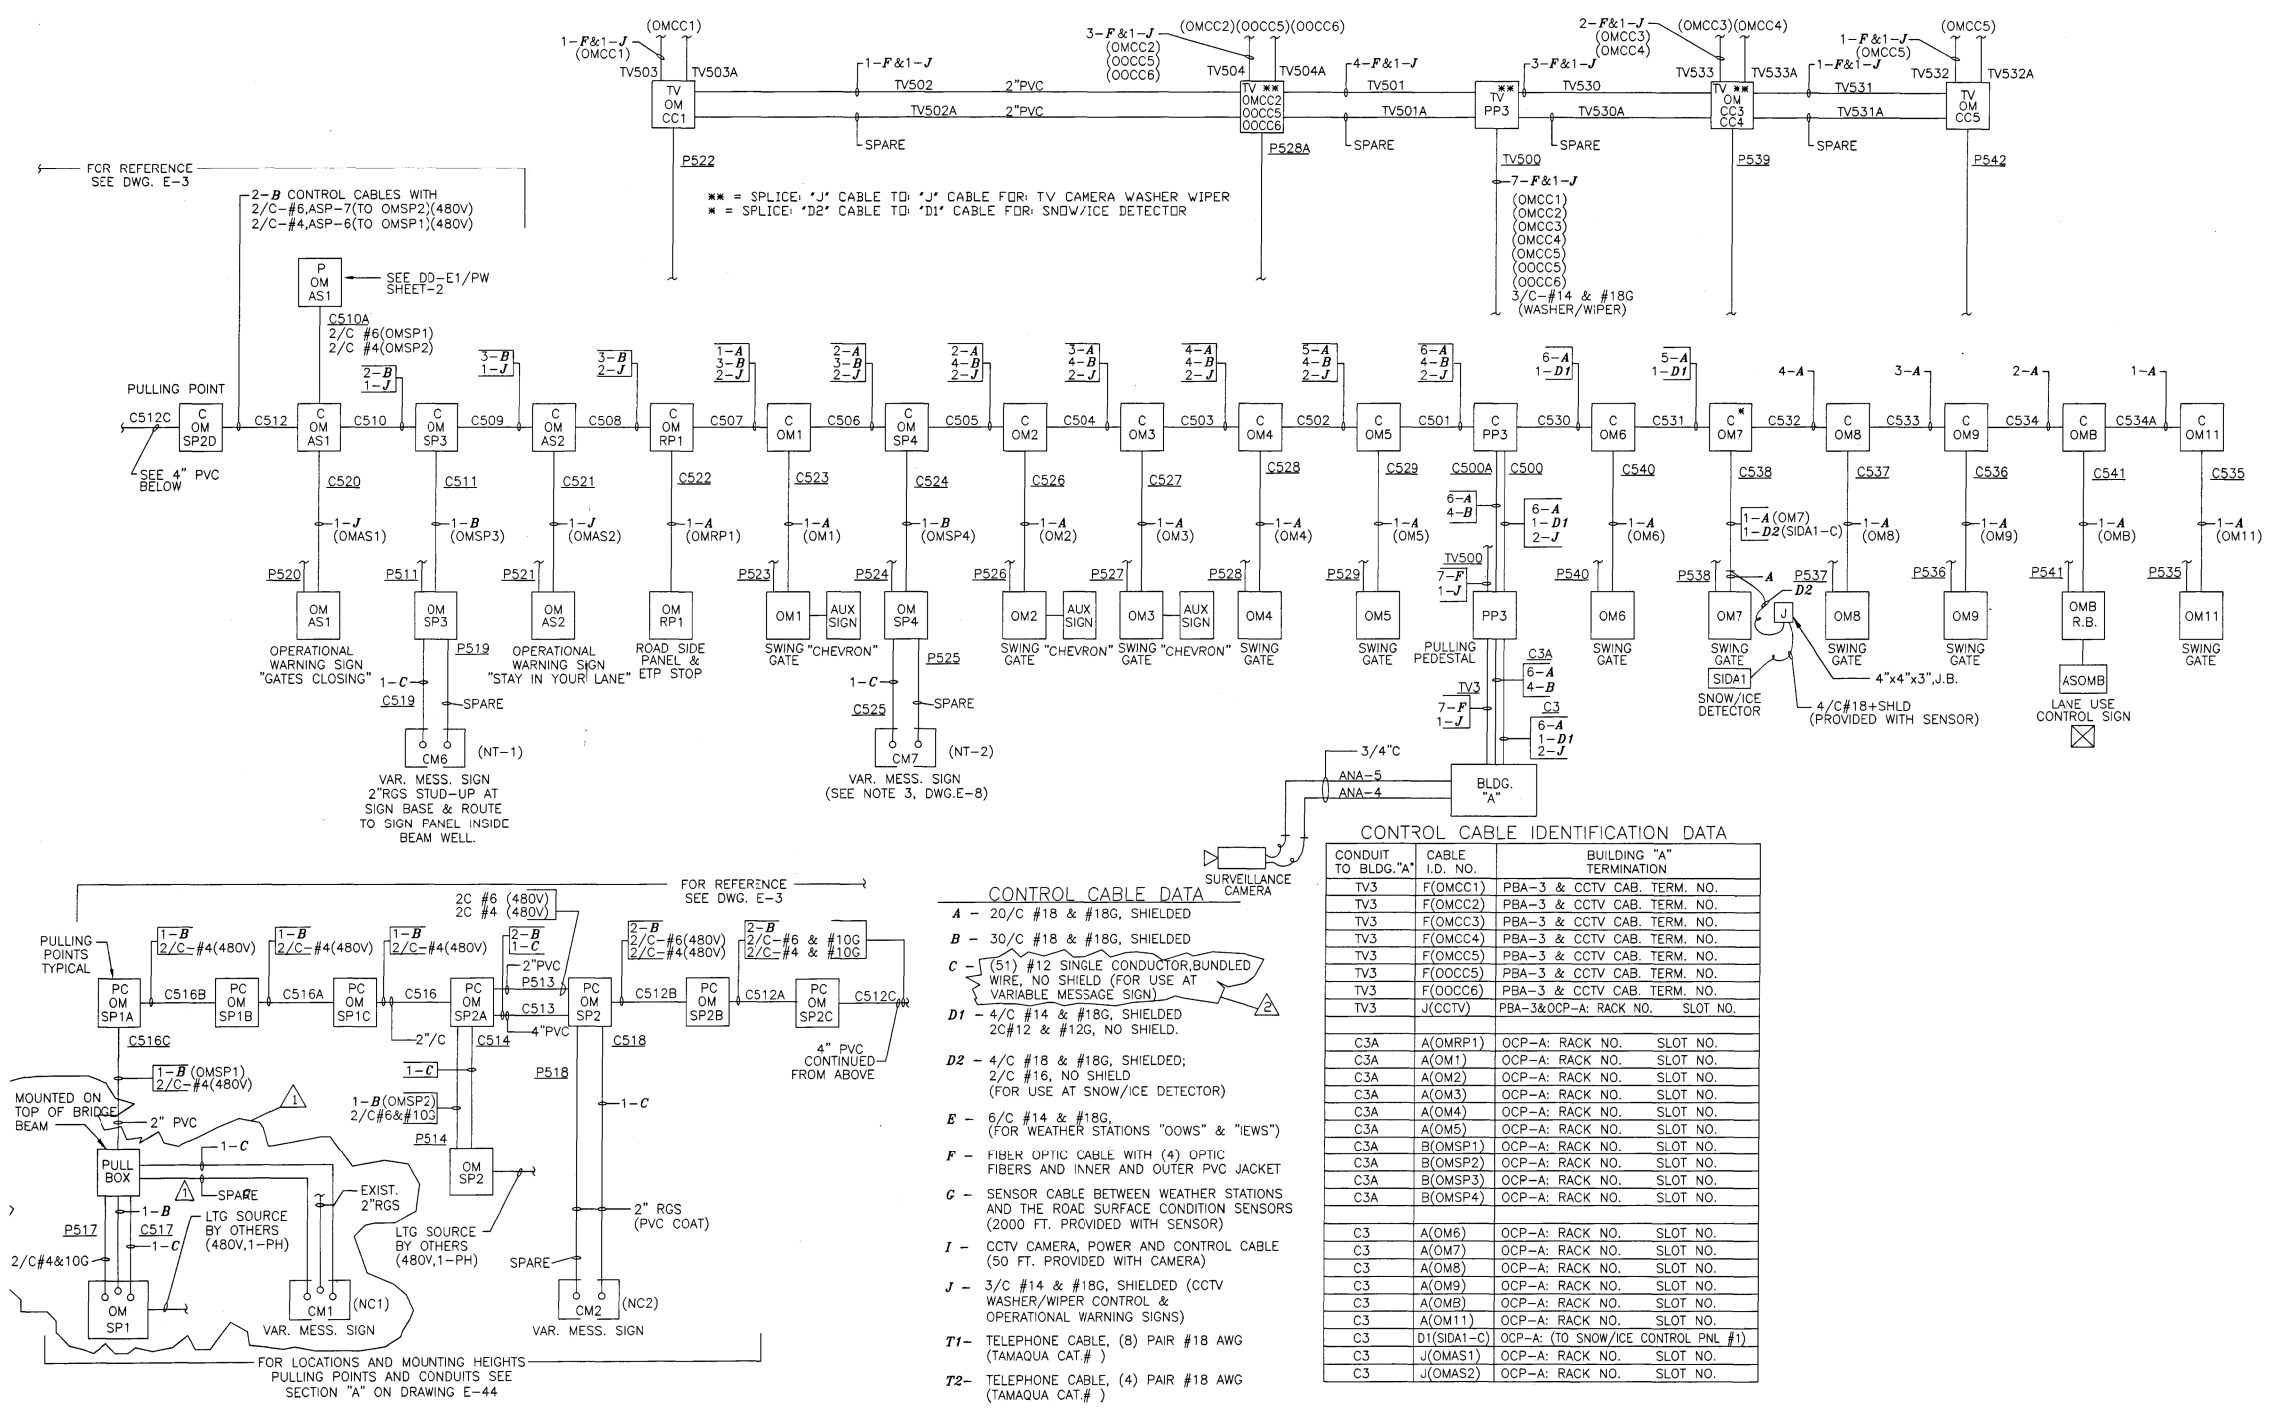

- NOTES:
1. THE ABOVE DRAWINGS REPRESENT AS LET DESIGN TO AID CONTRACTOR IN ASCERTAINING EXISTING CONDITIONS.
  2. CONTRACTOR SHALL CONTACT IDOT D1 TO REQUEST THE MOST UP TO DATE RECORD DRAWINGS AVAILABLE AT THE TIME OF LETTING.

FOR INFORMATION ONLY

J:\293\Task-2\CON\CADD\_Sheet\Sheet\17\_D160T93-sh1-details058.dgn



|                                        |                  |           |
|----------------------------------------|------------------|-----------|
| USER NAME = mgarvada                   | DESIGNED - DJ/AG | REVISED - |
| FILE NAME = 117_D160T93-sh1-details058 | DRAWN - DS/AS    | REVISED - |
| PLOT SCALE = 2.000000:1.000000         | CHECKED - 1Y     | REVISED - |
| PLOT DATE = 06-MAY-2015 15:30          | DATE - 5/6/2015  | REVISED - |


STATE OF ILLINOIS  
DEPARTMENT OF TRANSPORTATION

REMOTE BUILDING A KENNEDY NORTHWEST BOUND  
CONTROL CABLE WIRING

SCALE: NTS SHEET OF SHEETS STA. TO STA.

|                           |           |        |              |           |
|---------------------------|-----------|--------|--------------|-----------|
| F.A.I. RTE.               | SECTION   | COUNTY | TOTAL SHEETS | SHEET NO. |
| 90/94                     | 2012-0521 | COOK   | 165          | 117       |
| CONTRACT NO. 60T93        |           |        |              |           |
| ILLINOIS FED. AID PROJECT |           |        |              |           |

J:\293\Task-2\CON\CADD\_Sheet\s\18\_D160T93-sh1-details059.dgn

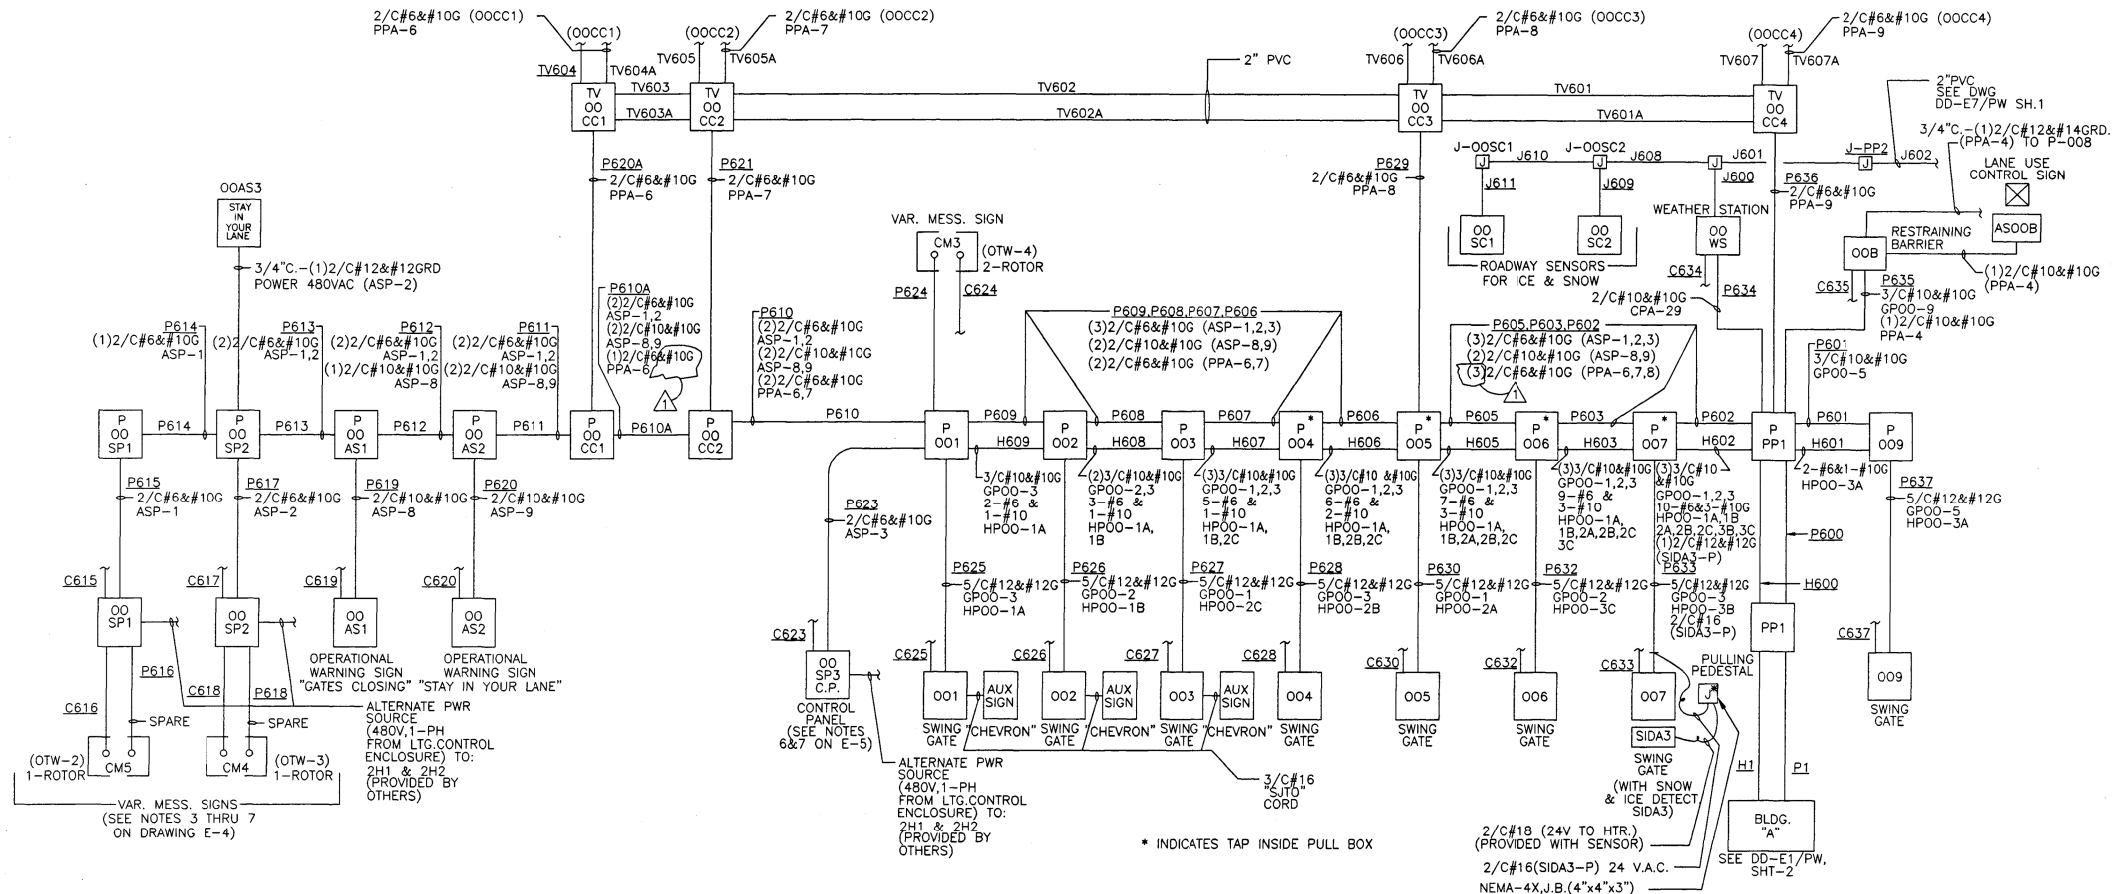

| 4" PVC: I.D.=3.826, AS=11.5 SQ. IN. |                      |              |
|-------------------------------------|----------------------|--------------|
| CONDUCTORS & VOLTAGE                | WIRE/CABLE NUMBER    | AREA SQ. IN. |
| CKT-1                               | HP00-1A,1B           | .24          |
| 3-#6&#1-#10G                        | (277V)               | .038         |
| 4-#6&#1-#10G                        | HP00-2A,2B,2C        | .32          |
|                                     | (277V)               | .038         |
| 4-#6&#1-#10G                        | HP00-3A,3B,3C        | .32          |
|                                     | (277V)               | .038         |
| 5/3/C#10&#10G                       | GP00-1,2,3,5,9       | 1.70         |
|                                     | (480V)               |              |
| 1/2/C#10&#10G                       | CPA-29               | .28          |
|                                     | (120V)               |              |
| 1/2/C#12&#12G                       | (SIDA3-P)            | .15          |
|                                     | (24V)                |              |
|                                     | TOTAL                | 3.124        |
| AREA SQ. IN. 4"PVC=11.5             | % FILL: 3.124 / 11.5 | =27%         |

| 4" PVC: I.D.=3.826, AS=11.5 SQ. IN. |                    |              |
|-------------------------------------|--------------------|--------------|
| CONDUCTORS & VOLTAGE                | WIRE/CABLE NUMBER  | AREA SQ. IN. |
| 3/2/C#6&#10G                        | ASP-1, 2, 3        | 1.44         |
|                                     | (480V)             |              |
| 2/2/C#10&#10G                       | ASP-8,9            | .56          |
|                                     | (480V)             |              |
| 4/2/C#6&#10G                        | PPA-6,7,8,9        | 1.92         |
|                                     | (120V)             |              |
| 1/2/C#10&#10G                       | PPA-4              | .28          |
|                                     | (120V)             |              |
|                                     | TOTAL              | 4.2          |
| AREA SQ. IN. 4"PVC=11.5             | % FILL: 4.2 / 11.5 | =37%         |

NOTES:

1. THE ABOVE DRAWINGS REPRESENT AS LET DESIGN TO AID CONTRACTOR IN ASCERTAINING EXISTING CONDITIONS.
2. CONTRACTOR SHALL CONTACT IDOT D1 TO REQUEST THE MOST UP TO DATE RECORD DRAWINGS AVAILABLE AT THE TIME OF LETTING.

FOR INFORMATION ONLY

**SINGH**  
SINGH - ASSOCIATES INC.  
CONSULTING ENGINEERS

|                                        |                  |           |
|----------------------------------------|------------------|-----------|
| USER NAME = mgarvido                   | DESIGNED - DJ/AG | REVISED - |
| FILE NAME = 118_D160T93-sh1-details059 | DRAWN - DS/AS    | REVISED - |
| PLOT SCALE = 2.000000:1.000000         | CHECKED - 1Y     | REVISED - |
| PLOT DATE = 06-MAY-2015 15:31          | DATE - 5/6/2015  | REVISED - |

STATE OF ILLINOIS  
DEPARTMENT OF TRANSPORTATION


REMOTE BUILDING A WEST BOUND ONTARIO/OHIO FEEDER  
POWER AND HEATER WIRING

SCALE: NTS SHEET OF SHEETS STA. TO STA.

RECORD  
DRAWING  
AUG 5 1997  
*Ken D. Bisher*

| F.A.I. RTE.               | SECTION   | COUNTY | TOTAL SHEETS | SHEET NO. |
|---------------------------|-----------|--------|--------------|-----------|
| 90/94                     | 2012-0521 | COOK   | 165          | 118       |
| CONTRACT NO. 60T93        |           |        |              |           |
| ILLINOIS FED. AID PROJECT |           |        |              |           |



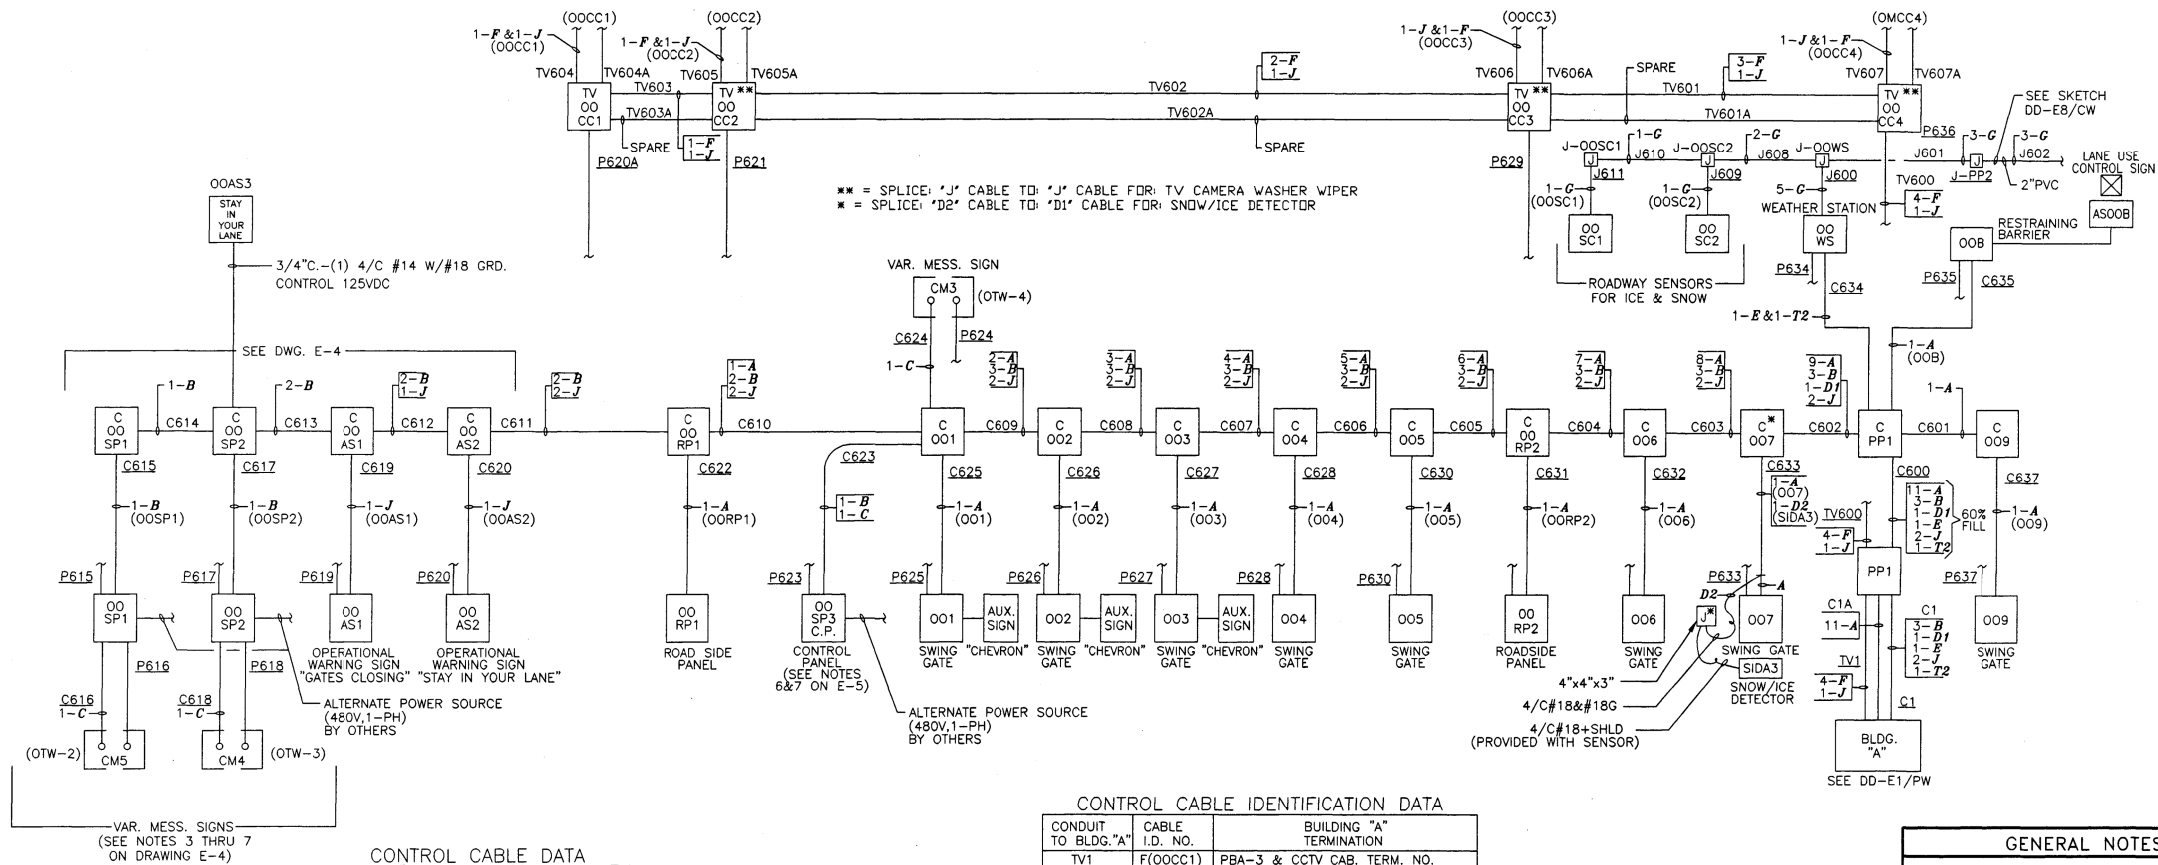

#### CONTROL CABLE DATA

A - 20/C #18 & #18G, SHIELDED

B - 30/C #18 & #18G, SHIELDED

C - (51) #12 SINGLE CONDUCTOR, BUNDLED WIRE, NO SHIELD (FOR USE AT VARIABLE MESSAGE SIGN)

D1 - 4/C #14 & #18G, SHIELDED; 2/C #12 & #12G, NO SHIELD

D2 - 4/C #18 & #18G, SHIELDED; 2/C #16, NO SHIELD (FOR USE AT SNOW/ICE DETECTOR)

E - 6/C #14 & #18G, (FOR WEATHER STATIONS "OOWS" & "IEWS")

F - FIBER OPTIC CABLE WITH (4) OPTIC FIBERS AND INNER AND OUTER PVC JACKET

G - SENSOR CABLE BETWEEN WEATHER STATIONS AND THE ROAD SURFACE CONDITION SENSORS (2000 FT. PROVIDED WITH SENSOR)

I - CCTV CAMERA, POWER AND CONTROL CABLE (50 FT. PROVIDED WITH CAMERA)

J - 3/C #14 & #18G, SHIELDED (CCTV WASHER/WIPER CONTROL & OPERATIONAL WARNING SIGNS)

T1 - TELEPHONE CABLE, (8) PAIR #18 AWG (TAMAQUA CAT.# )

T2 - TELEPHONE CABLE, (4) PAIR #18 AWG (TAMAQUA CAT.# )

#### CONTROL CABLE IDENTIFICATION DATA

| CONDUIT TO BLDG. "A" | CABLE I.D. NO. | BUILDING "A" TERMINATION                |
|----------------------|----------------|-----------------------------------------|
| TV1                  | F(OOCC1)       | PBA-3 & CCTV CAB. TERM. NO.             |
| TV1                  | F(OOCC2)       | PBA-3 & CCTV CAB. TERM. NO.             |
| TV1                  | F(OOCC3)       | PBA-3 & CCTV CAB. TERM. NO.             |
| TV1                  | F(OOCC4)       | PBA-3 & CCTV CAB. TERM. NO.             |
| TV1                  | J(CCTV)        | PBA-3 & CCTV CAB. TO OCP-A              |
| C1A                  | A(OO1)         | OCP-A: RACK NO. SLOT NO.                |
| C1A                  | A(OO2)         | OCP-A: RACK NO. SLOT NO.                |
| C1A                  | A(OO3)         | OCP-A: RACK NO. SLOT NO.                |
| C1A                  | A(OO4)         | OCP-A: RACK NO. SLOT NO.                |
| C1A                  | A(OO5)         | OCP-A: RACK NO. SLOT NO.                |
| C1A                  | A(OORP2)       | OCP-A: RACK NO. SLOT NO.                |
| C1A                  | A(OO6)         | OCP-A: RACK NO. SLOT NO.                |
| C1A                  | A(OO7)         | OCP-A: RACK NO. SLOT NO.                |
| C1A                  | A(OO9)         | OCP-A: RACK NO. SLOT NO.                |
| C1A                  | A(OOB)         | OCP-A: RACK NO. SLOT NO.                |
| C1A                  | A(OORP1)       | OCP-A: RACK NO. SLOT NO.                |
| C1                   | E(OOWS)        | OCP-A: RACK NO. SLOT NO.                |
| C1                   | B(OOSP1)       | OCP-A: RACK NO. SLOT NO.                |
| C1                   | B(OOSP2)       | OCP-A: RACK NO. SLOT NO.                |
| C1                   | B(OOSP3)       | OCP-A: RACK NO. SLOT NO.                |
| C1                   | D1(SIDA3-C)    | OCP-A TO SNOW/ICE DETECTOR CONT. PNL #3 |
| C1                   | J(OOAS1)       | OCP-A: RACK NO. SLOT NO.                |
| C1                   | J(OOAS2)       | OCP-A: RACK NO. SLOT NO.                |
| C1                   | T2(OOWS)       | OCP-A (TO TELE. CABINET TTCA)           |

#### GENERAL NOTES

- DESIGNATIONS IN PARENTHESES AT CONTROL CABLE INDICATIONS ARE FOR CABLE IDENTIFICATION PURPOSES.
- STRANDED CONDUCTOR CABLE SHALL BE TERMINATED BY LUGS, CUP WASHERS, OR PRESSURE TYPE CONNECTORS. STRANDED CABLES SHALL NOT BE WRAPPED AROUND SCREW TYPE TERMINALS.

RECORD  
DRAWING  
AUG 5 1997  
Ken D. Fisher

#### NOTES:

- THE ABOVE DRAWINGS REPRESENT AS LET DESIGN TO AID CONTRACTOR IN ASCERTAINING EXISTING CONDITIONS.
- CONTRACTOR SHALL CONTACT IDOT D1 TO REQUEST THE MOST UP TO DATE RECORD DRAWINGS AVAILABLE AT THE TIME OF LETTING.

FOR INFORMATION ONLY

**SINGH**  
SINGH - ASSOCIATES INC.  
CONSULTING ENGINEERS

USER NAME = mgarvada  
FILE NAME = 119.D160T93-shd-details060  
PLOT SCALE = 2.000000:1.000000  
PLOT DATE = 06-MAY-2015 15:32

DESIGNED - DJ/AG  
DRAWN - DS/AS  
CHECKED - 1Y  
DATE - 5/6/2015

REVISED -  
REVISED -  
REVISED -  
REVISED -

STATE OF ILLINOIS  
DEPARTMENT OF TRANSPORTATION

REMOTE BUILDING A WEST BOUND ONTARIO/OHIO  
FEEDER CONTROL CABLE WIRING

SCALE: NTS SHEET OF SHEETS STA. TO STA.

|                           |           |        |              |           |
|---------------------------|-----------|--------|--------------|-----------|
| F.A.I. RTE.               | SECTION   | COUNTY | TOTAL SHEETS | SHEET NO. |
| 90/94                     | 2012-0521 | COOK   | 165          | 119       |
| CONTRACT NO. 60T93        |           |        |              |           |
| ILLINOIS FED. AID PROJECT |           |        |              |           |

J:\293\Task-2\CON\CADD\_Sheet\N20.Die0193-sh1-details061.dgn

### CHANGEABLE MESSAGE SIGN AUXILIARY FEEDER SCHEDULE



|      |                               |
|------|-------------------------------|
| CM-8 | FEED FROM IDOT PWR CENTER 'N' |
| CM-9 | FEED FROM IDOT PWR CENTER 'N' |

### CABLE SCHEDULE

| TAG | NO. & WIRE SIZE                | REMARKS |
|-----|--------------------------------|---------|
| C1  | 3#6, 1#10 GND.                 |         |
| C2  | 2#6, 1#10 GND.                 |         |
| C3  | 3#4, 1#6 GND.                  |         |
| C4  | 2#1/0, 1#4 GND.                |         |
| C5  | 4#500MCM, 1#1/0 GND.           |         |
| C6  | 3#6, 1#10 GND.                 |         |
| C7  | 3#2, 1#6 GND. **2#2, 1#8GRD.   |         |
| C8  | 1#4/0 GROUND WIRE              |         |
| C9  | 3#8, 1#10 GND.                 |         |
| C10 | 4#3/0 1#6 GND.                 |         |
| C11 | 2#2, 1#6 GND. **2#1, 1#8GRD.   |         |
| C12 | 3#2/0 1#4 GND. **3#2, 1#8GRD.  |         |
| C13 | 2 SETS OF 4#250MCM, 1#2 GND/EA |         |
| C14 | 3#1, 1#6 GND.                  |         |
| C15 | 3#10, 1#10 GND.                |         |
| C16 | 3#12, 1#12 GND.                |         |
| C17 | 2#4/0, 1#4 GND.                |         |
| C18 | 2#10, 1#10 GND.                |         |
| C19 | 2#8, 1#10 GND.                 |         |
| C20 | 4#10, 1#10 GND.                |         |
| C21 | 2/C #4, 1#10 GND.              |         |

#### NOTES:

- 1.) POWER LINES TO INDIVIDUAL GATE CONTROLS TO BE PULLED THROUGH EXISTING 4" CONDUIT.
- 2.) \* INDICATES PANEL PREFIX.
- 3.) CIRCUIT FROM ROADWAY LIGHTING CONTROL. SEE CM SIGN SCHEDULE.
- 4.) NUMBER SHOWN ADJACENT TO SWING GATE MOTOR IDENTIFIES CIRCUIT NUMBER OF THREE PHASE BREAKER IN RESPECTIVE GATE HEATER PANEL. LETTER INDICATES PHASE TO BE USED TO FEED THE 277V GATE HEATER. EXAMPLE: SWING GATE DS3 IS FED FROM PANEL HPDS, CIRCUIT NUMBER SEVEN, PHASE A (SWING GATES DS4 & DS5 ARE FED FROM PHASE B AND PHASE C OF THE SAME CIRCUIT). SEE TYP. WIRING DIAGRAM ON DWG. E-89.

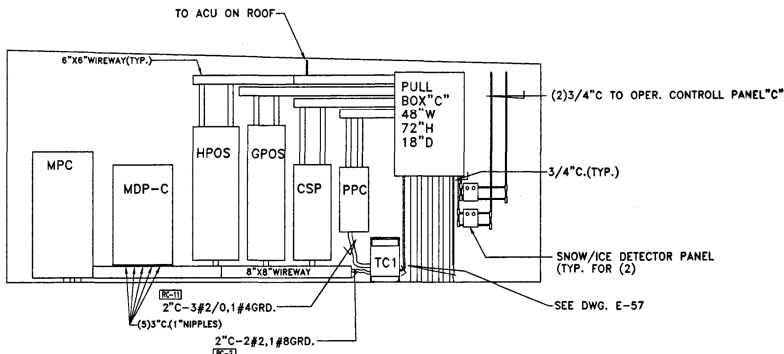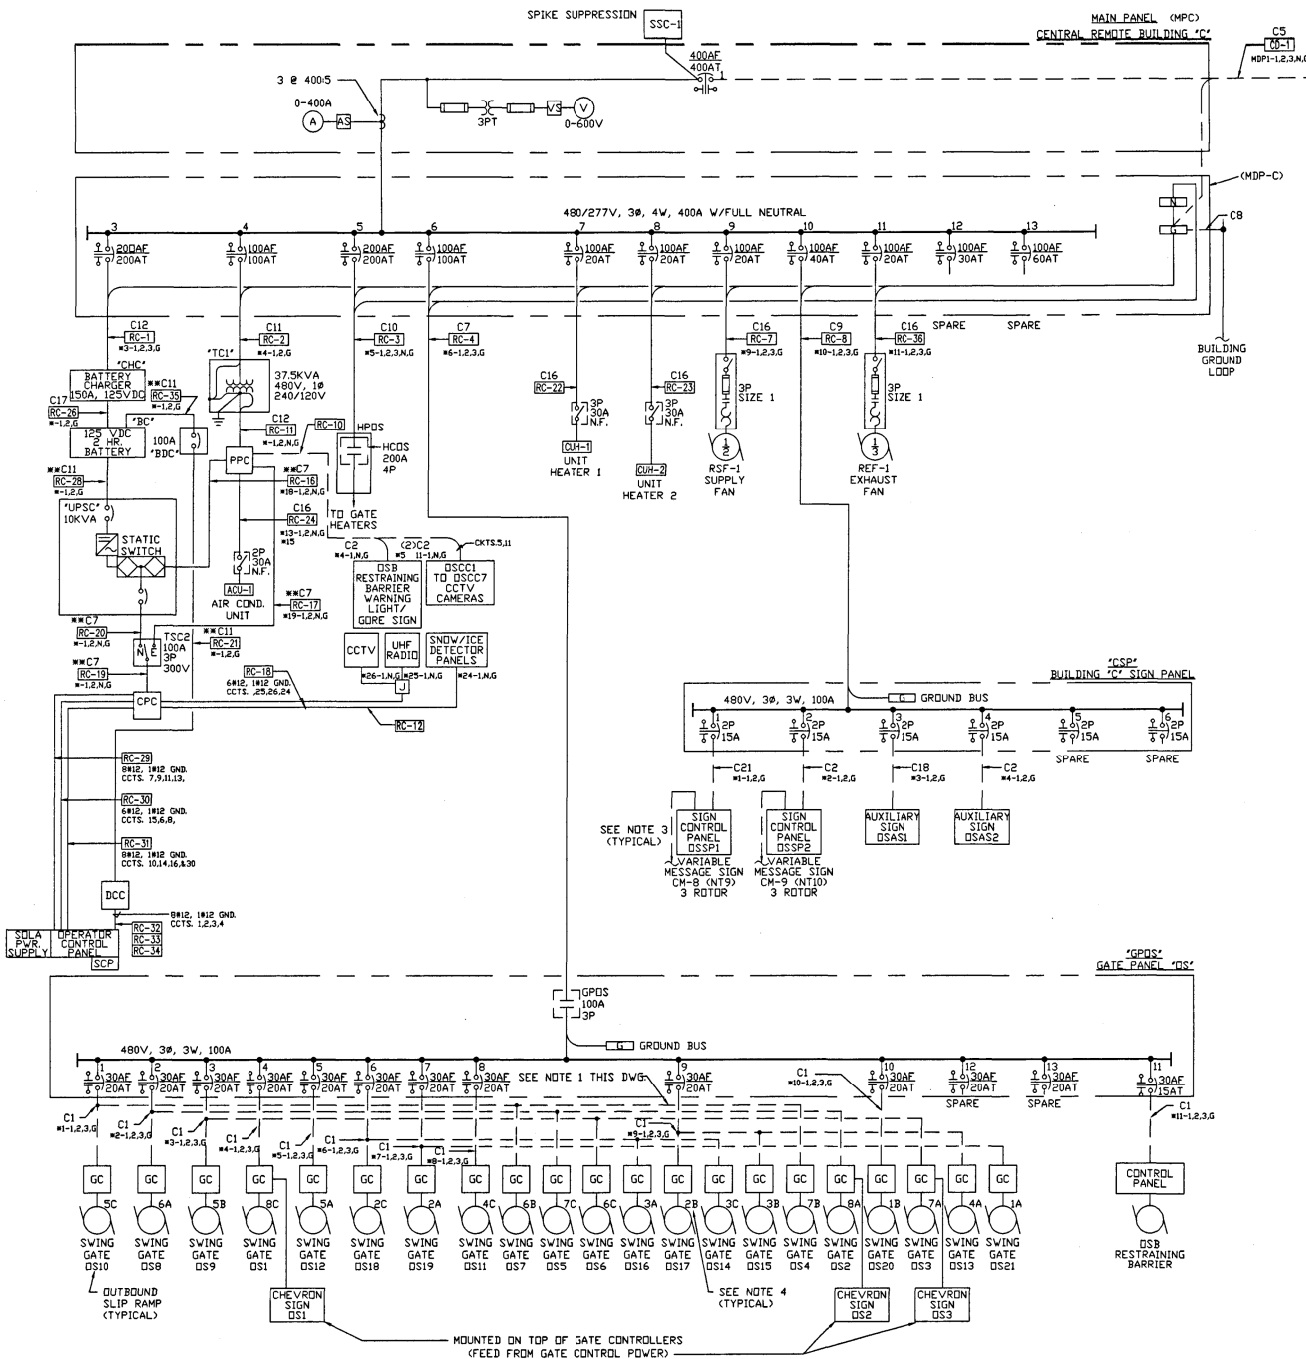

BLDG. C  
SECTION A-A

RECORD  
DRAWING  
AUG 5 1997

Ken D. Bisher

#### NOTES:

1. THE ABOVE DRAWINGS REPRESENT AS LET DESIGN TO AID CONTRACTOR IN ASCERTAINING EXISTING CONDITIONS.
2. CONTRACTOR SHALL CONTACT IDOT D1 TO REQUEST THE MOST UP TO DATE RECORD DRAWINGS AVAILABLE AT THE TIME OF LETTING.

FOR INFORMATION ONLY

**SINGH**  
SINGH - ASSOCIATES INC.  
CONSULTING ENGINEERS

USER NAME = mgarvido  
FILE NAME = 120.D160T93-sh1-details061  
PLOT SCALE = 2.000000:1.000000  
PLOT DATE = 06-MAY-2015 15:33

DESIGNED - DJ/AG  
DRAWN - DS/AS  
CHECKED - 1Y  
DATE - 5/6/2015


REVISED -  
REVISED -  
REVISED -  
REVISED -

STATE OF ILLINOIS  
DEPARTMENT OF TRANSPORTATION


REMOTE BUILDING C SINGLE LINE DIAGRAM

SCALE: NTS SHEET OF SHEETS STA. TO STA.


|                           |           |        |              |           |
|---------------------------|-----------|--------|--------------|-----------|
| F.A.I. RTE.               | SECTION   | COUNTY | TOTAL SHEETS | SHEET NO. |
| 90/94                     | 2012-0521 | COOK   | 165          | 120       |
| CONTRACT NO. 60T93        |           |        |              |           |
| ILLINOIS FED. AID PROJECT |           |        |              |           |

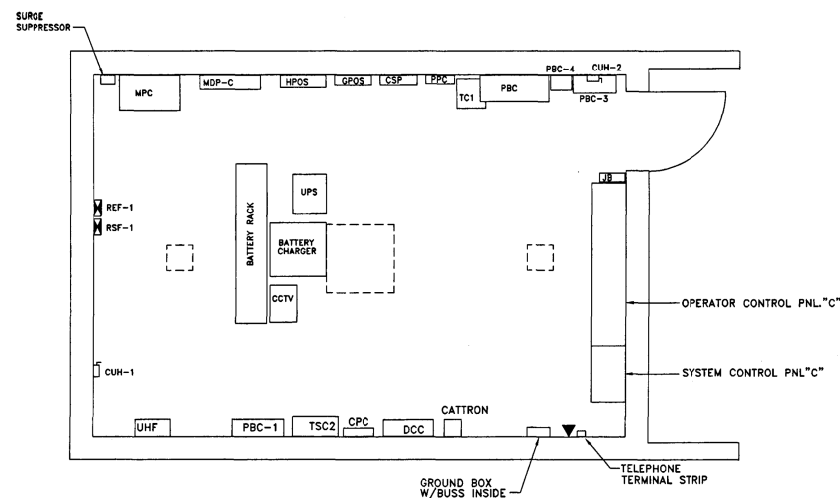

BLDG. C  
EQUIPMENT LAYOUT

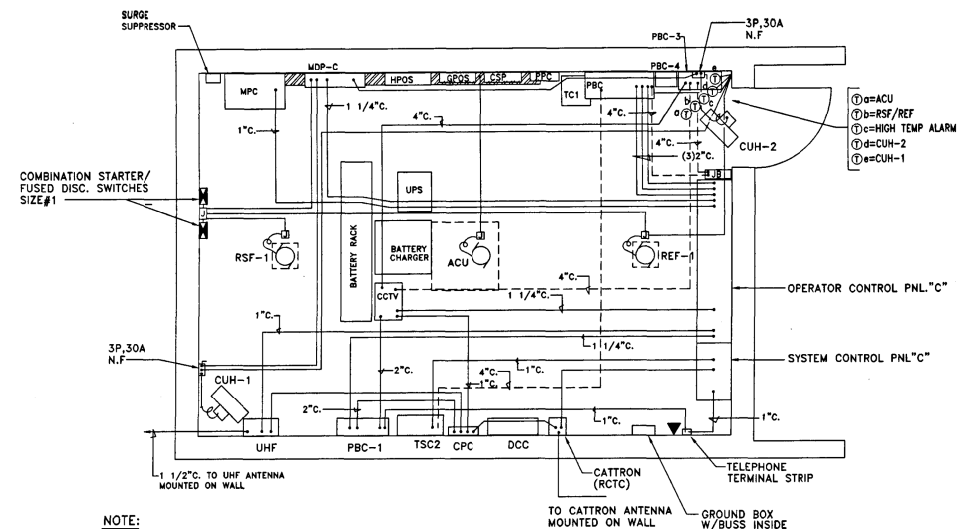

BLDG. C  
COMMUNICATIONS  
AND HVAC

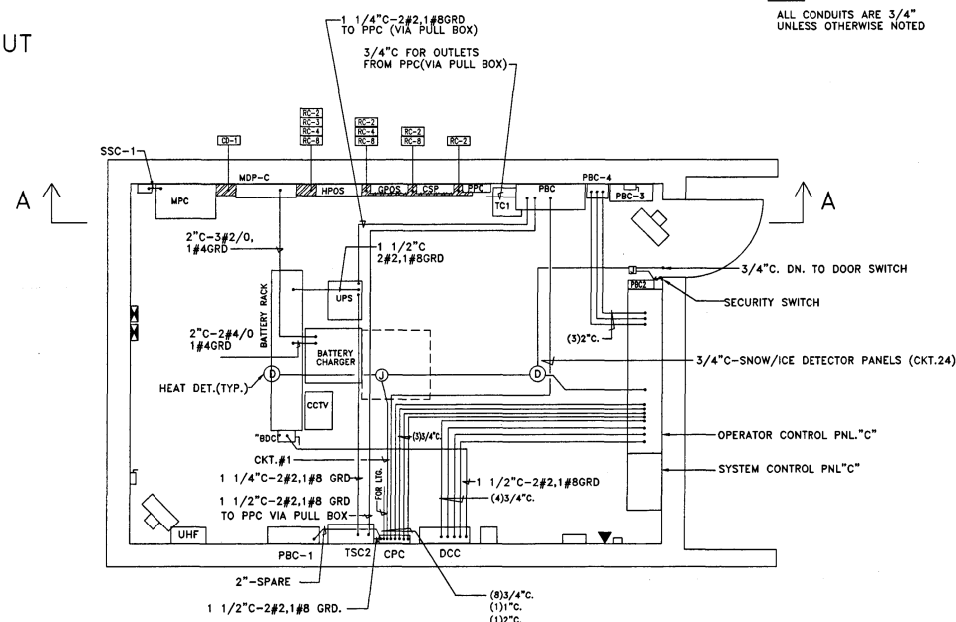

BLDG. C  
FEEDERS AND POWER

NOTES:

1. THE ABOVE DRAWINGS REPRESENT AS LET DESIGN TO AID CONTRACTOR IN ASCERTAINING EXISTING CONDITIONS.
2. CONTRACTOR SHALL CONTACT IDOT D1 TO REQUEST THE MOST UP TO DATE RECORD DRAWINGS AVAILABLE AT THE TIME OF LETTING.

RECORD  
DRAWING  
AUG 5 1997  
*Kenn D. Bisher*

**FOR INFORMATION ONLY**

**SINGH**  
SINGH - ASSOCIATES, INC.  
CONSULTING ENGINEERS

|                                        |                  |           |
|----------------------------------------|------------------|-----------|
| USER NAME = mgarvito                   | DESIGNED - DJ/AG | REVISED - |
| FILE NAME = 121.D160T93-sht-details062 | DRAWN - DS/AS    | REVISED - |
| PLOT SCALE = 2.000000:1.000000         | CHECKED - 1Y     | REVISED - |
| PLOT DATE = 06-MAY-2015 15:34          | DATE - 5/6/2015  | REVISED - |

STATE OF ILLINOIS  
DEPARTMENT OF TRANSPORTATION

REMOTE BUILDING C EQUIPMENT LAYOUT

SCALE: NTS SHEET OF SHEETS STA. TO STA.

|                           |           |        |              |           |
|---------------------------|-----------|--------|--------------|-----------|
| F.A.I. RTE.               | SECTION   | COUNTY | TOTAL SHEETS | SHEET NO. |
| 90/94                     | 2012-0521 | COOK   | 165          | 121       |
| CONTRACT NO. 60T93        |           |        |              |           |
| ILLINOIS FED. AID PROJECT |           |        |              |           |

J:\293\Task-2\CON\CADD\_Sheet\22.Die0T93-sh1-details063.dgn

#### NOTES:

- THE ABOVE DRAWINGS REPRESENT AS LET DESIGN TO AID CONTRACTOR IN ASCERTAINING EXISTING CONDITIONS.
- CONTRACTOR SHALL CONTACT IDOT D1 TO REQUEST THE MOST UP TO DATE RECORD DRAWINGS AVAILABLE AT THE TIME OF LETTING.

**SINGH**  
SINGH - ASSOCIATES INC.  
CONSULTING ENGINEERS

|            |                              |
|------------|------------------------------|
| USER NAME  | = mgarvada                   |
| FILE NAME  | = 122.Die0T93-sh1-details063 |
| PLOT SCALE | = 2.000000:1.000000          |
| PLOT DATE  | = 06-MAY-2015 15:34          |

|          |            |
|----------|------------|
| DESIGNED | - DJ/AG    |
| DRAWN    | - DS/AS    |
| CHECKED  | - 1Y       |
| DATE     | - 5/6/2015 |


|         |   |
|---------|---|
| REVISED | - |
| REVISED | - |
| REVISED | - |
| REVISED | - |


STATE OF ILLINOIS  
DEPARTMENT OF TRANSPORTATION

REMOTE BUILDING C OUTBOUND SLIP RAMP  
POWER AND HEATER WIRING

SCALE: NTS SHEET OF SHEETS STA. TO STA.

|                           |           |        |              |           |
|---------------------------|-----------|--------|--------------|-----------|
| F.A.I. RTE.               | SECTION   | COUNTY | TOTAL SHEETS | SHEET NO. |
| 90/94                     | 2012-0521 | COOK   | 165          | 122       |
| CONTRACT NO. 60T93        |           |        |              |           |
| ILLINOIS FED. AID PROJECT |           |        |              |           |

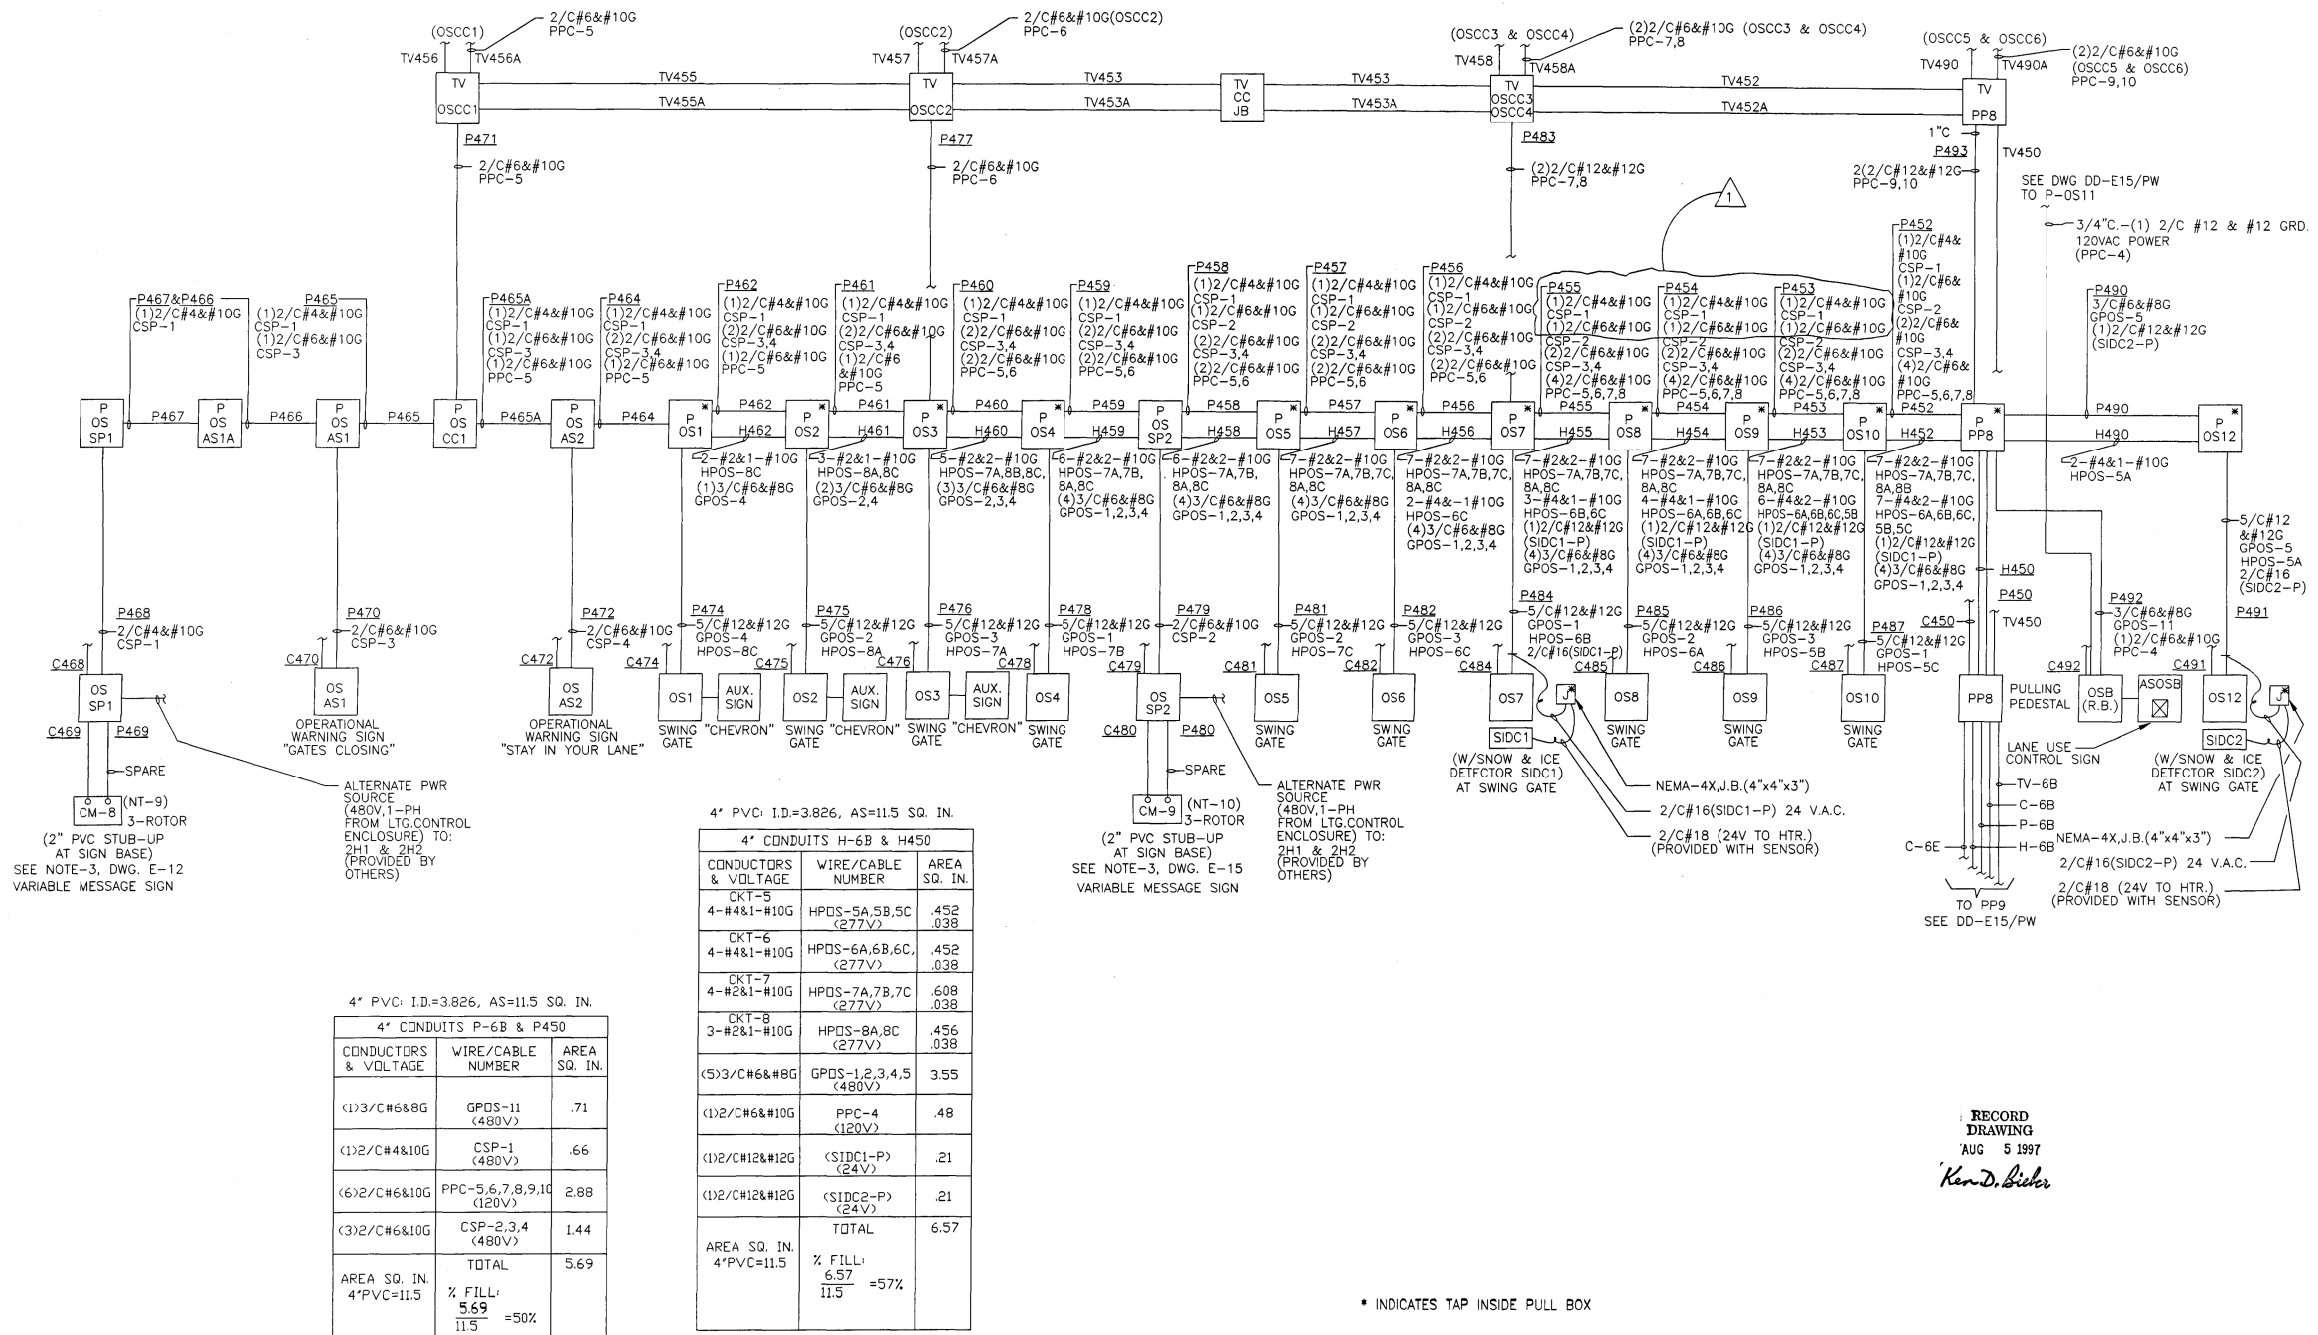

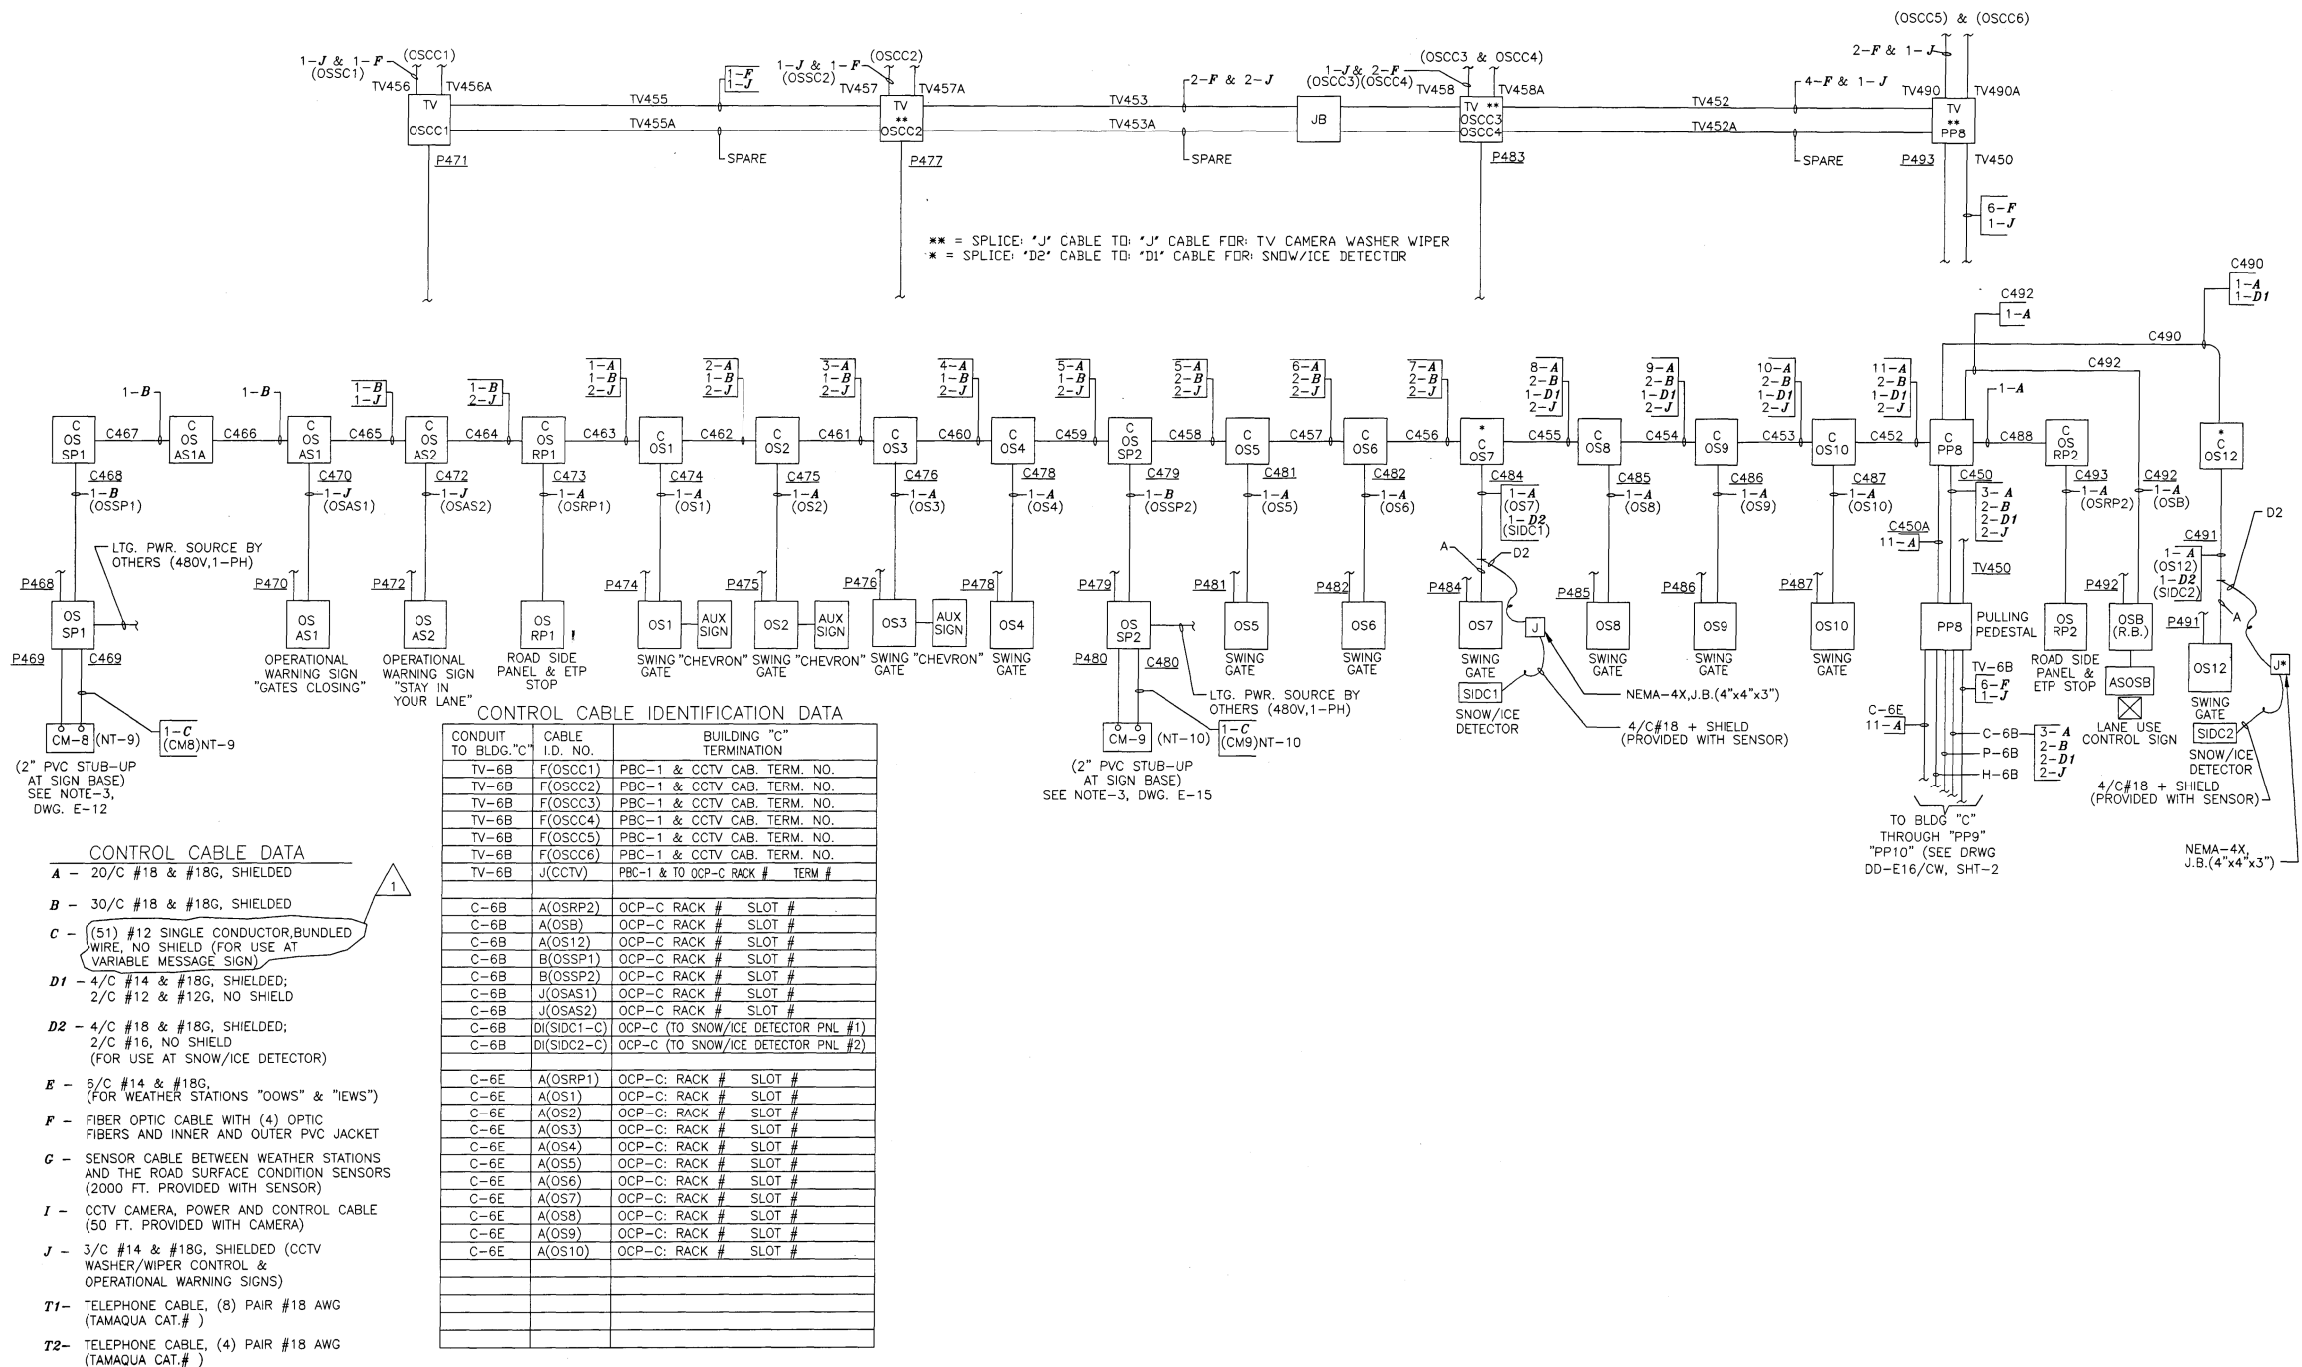

# NOTES:

- THE ABOVE DRAWINGS REPRESENT AS LET DESIGN TO AID CONTRACTOR IN ASCERTAINING EXISTING CONDITIONS.
- CONTRACTOR SHALL CONTACT IDOT D1 TO REQUEST THE MOST UP TO DATE RECORD DRAWINGS AVAILABLE AT THE TIME OF LETTING.

**FOR INFORMATION ONLY**

**SINGH**  
SINGH - ASSOCIATES INC.  
CONSULTING ENGINEERS

USER NAME = mgarvada  
FILE NAME = 123.D160T93-sh1-details064  
PLOT SCALE = 2.000000:1.000000  
PLOT DATE = 06-MAY-2015 15:35

DESIGNED - DJ/AG  
DRAWN - DS/AS  
CHECKED - 1Y  
DATE - 5/6/2015


REVISED -  
REVISED -  
REVISED -  
REVISED -

STATE OF ILLINOIS  
DEPARTMENT OF TRANSPORTATION

REMOTE BUILDING C OUTBOUND SLIP RAMP CONTROL CABLE WIRING

SCALE: NTS SHEET OF SHEETS STA. TO STA.


| F.A.I. RTE.               | SECTION   | COUNTY | TOTAL SHEETS | SHEET NO. |
|---------------------------|-----------|--------|--------------|-----------|
| 90/94                     | 2012-0521 | COOK   | 165          | 123       |
| CONTRACT NO. 60T93        |           |        |              |           |
| ILLINOIS FED. AID PROJECT |           |        |              |           |

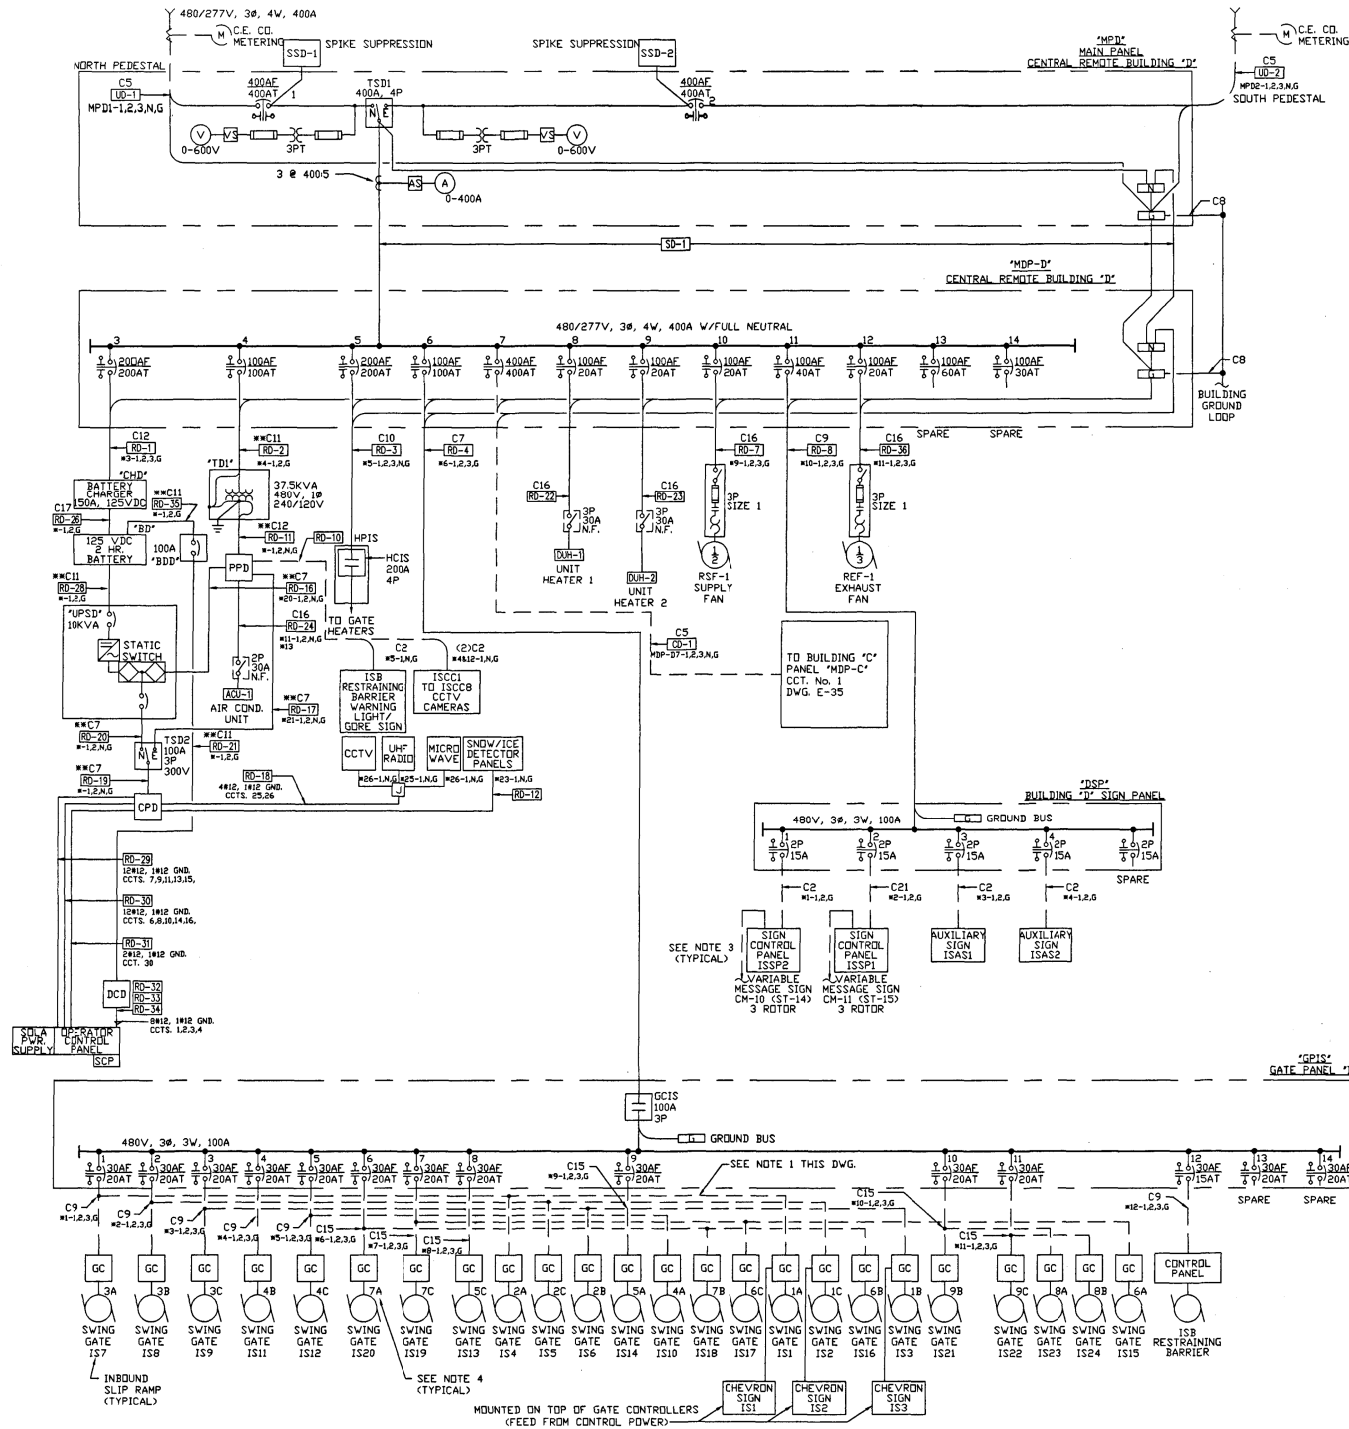

| CHANGEABLE MESSAGE SIGN<br>AUXILIARY FEEDER SCHEDULE |                               |
|------------------------------------------------------|-------------------------------|
| CM-10                                                | FEED FROM IDOT PWR CENTER 'M' |
| CM-11                                                | FEED FROM IDOT PWR CENTER 'L' |

| CABLE SCHEDULE |                                |                          |
|----------------|--------------------------------|--------------------------|
| TAG            | NO. & WIRE SIZE                | REMARKS                  |
| C1             | 3#6, 1#10 GND.                 | MULTI-CONDUCTOR<br>CABLE |
| C2             | 2#6, 1#10 GND.                 |                          |
| C3             | 3#4, 1#6 GND.                  |                          |
| C4             | 2#1/0, 1#4 GND.                |                          |
| C5             | 4#500MCM, 1#1/0 GND.           |                          |
| C6             | 3#6, 1#10 GND.                 |                          |
| C7             | 3#2, 1#8 GND. **2#21#8GND.     |                          |
| C8             | 1#4/0 GROUND WIRE              |                          |
| C9             | 3#8, 1#10 GND.                 |                          |
| C10            | 4#3/0 1#6 GND.                 |                          |
| C11            | 2#2, 1#8 GND. **2#11#8GND.     |                          |
| C12            | 3#2/0 1#4 GND. **3#21#4GND.    |                          |
| C13            | 8 SETS OF 4#250MCM, 1#2 GND/EA |                          |
| C14            | 3#1, 1#6 GND.                  |                          |
| C15            | 3#10, 1#10 GND.                |                          |
| C16            | 3#12, 1#12 GND.                |                          |
| C17            | 2#4/0, 1#4 GND.                |                          |
| C18            | 2#10, 1#10 GND.                |                          |
| C19            | 2#8, 1#10 GND.                 |                          |
| C20            | 4#10, 1#10 GND.                |                          |
| C21            | 2/C #4, 1#10 GND.              |                          |

- NOTES:
- 1.) POWER LINES TO INDIVIDUAL GATE CONTROLS TO BE PULLED THROUGH EXISTING 4" CONDUIT.
  - 2.) \* INDICATES PANEL PREFIX.
  - 3.) CIRCUIT FROM ROADWAY LIGHTING CONTROL, SEE DM SIGN SCHEDULE.
  - 4.) NUMBER SHOWN ADJACENT TO SWING GATE MOTOR IDENTIFIES CIRCUIT NUMBER OF THREE PHASE BREAKER IN RESPECTIVE GATE HEATER PANEL. LETTER INDICATES PHASE TO BE USED TO FEED THE 277V GATE HEATER. EXAMPLE: SWING GATE IS20 IS FED FROM PANEL HPIS, CIRCUIT NUMBER SEVEN, PHASE A (SWING GATES IS18 & IS19 ARE FED FROM PHASE B AND PHASE C OF THE SAME CIRCUIT). SEE TYP. WIRING DIAGRAM ON DWG. E-89.

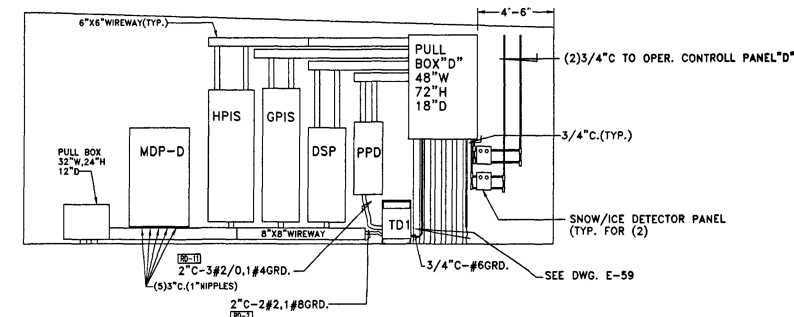

NOTES:

1. THE ABOVE DRAWINGS REPRESENT AS LET DESIGN TO AID CONTRACTOR IN ASCERTAINING EXISTING CONDITIONS.
2. CONTRACTOR SHALL CONTACT IDOT D1 TO REQUEST THE MOST UP TO DATE RECORD DRAWINGS AVAILABLE AT THE TIME OF LETTING.

FOR INFORMATION ONLY

**SINGH**  
SINGH - ASSOCIATES INC.  
CONSULTING ENGINEERS

USER NAME = mgarvida  
FILE NAME = 124.0160T93-sht-details065  
PLOT SCALE = 2.000000:1.000000  
PLOT DATE = 06-MAY-2015 15:36

DESIGNED - DJ/AG  
DRAWN - DS/AS  
CHECKED - 1Y  
DATE - 5/6/2015

REVISED -  
REVISED -  
REVISED -  
REVISED -


STATE OF ILLINOIS  
DEPARTMENT OF TRANSPORTATION

REMOTE BUILDING D SINGLE LINE DIAGRAM


SCALE: NTS SHEET OF SHEETS STA. TO STA.

|                           |           |        |              |           |
|---------------------------|-----------|--------|--------------|-----------|
| F.A.I. RTE.               | SECTION   | COUNTY | TOTAL SHEETS | SHEET NO. |
| 90/94                     | 2012-0521 | COOK   | 165          | 124       |
| CONTRACT NO. 60T93        |           |        |              |           |
| ILLINOIS FED. AID PROJECT |           |        |              |           |




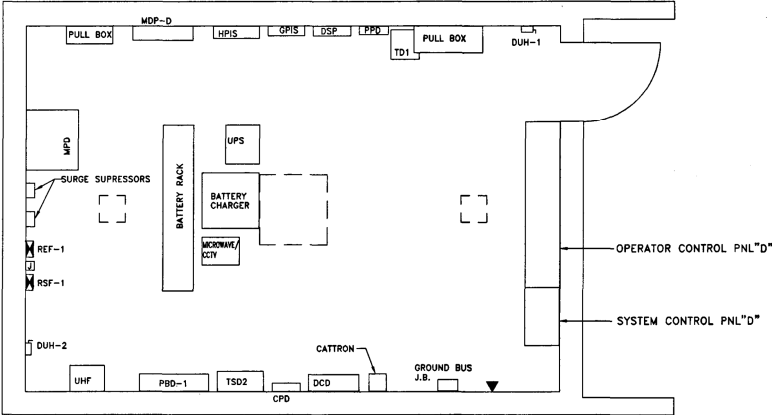

BLDG. D  
EQUIPMENT LAYOUT

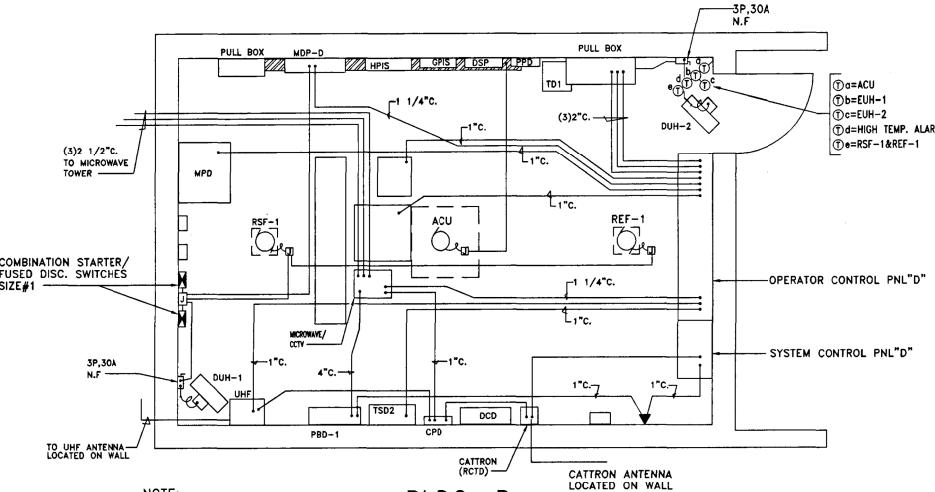

BLDG. D  
COMMUNICATIONS  
AND HVAC

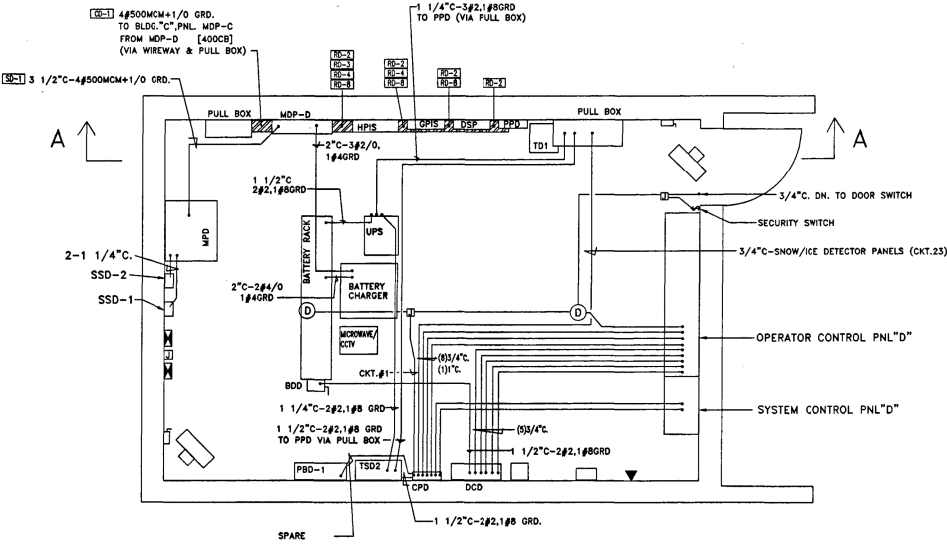

BLDG. D  
FEEDERS AND POWER

- NOTES:
1. THE ABOVE DRAWINGS REPRESENT AS LET DESIGN TO AID CONTRACTOR IN ASCERTAINING EXISTING CONDITIONS.
  2. CONTRACTOR SHALL CONTACT IDOT D1 TO REQUEST THE MOST UP TO DATE RECORD DRAWINGS AVAILABLE AT THE TIME OF LETTING.

FOR INFORMATION ONLY

RECORD  
DRAWING  
AUG 5 1997  
*Kan D. Bisher*

J:\293\Task-2\CON\CADD\_Sheet\25.D160T93-sh1-details066.dgn

**SINGH**  
SINGH - ASSOCIATES INC.  
CONSULTING ENGINEERS


|                                        |                  |           |
|----------------------------------------|------------------|-----------|
| USER NAME = mgarvada                   | DESIGNED - DJ/AG | REVISED - |
| FILE NAME = 125.D160T93-sh1-details066 | DRAWN - DS/AS    | REVISED - |
| PLOT SCALE = 2.000000:1.000000         | CHECKED - 1Y     | REVISED - |
| PLOT DATE = 06-MAY-2015 15:37          | DATE - 5/6/2015  | REVISED - |

STATE OF ILLINOIS  
DEPARTMENT OF TRANSPORTATION

REMOTE BUILDING D EQUIPMENT LAYOUT

SCALE: NTS SHEET OF SHEETS STA. TO STA.

| F.A.I. RTE.               | SECTION   | COUNTY | TOTAL SHEETS | SHEET NO. |
|---------------------------|-----------|--------|--------------|-----------|
| 90/94                     | 2012-0521 | COOK   | 165          | 125       |
| CONTRACT NO. 60T93        |           |        |              |           |
| ILLINOIS FED. AID PROJECT |           |        |              |           |

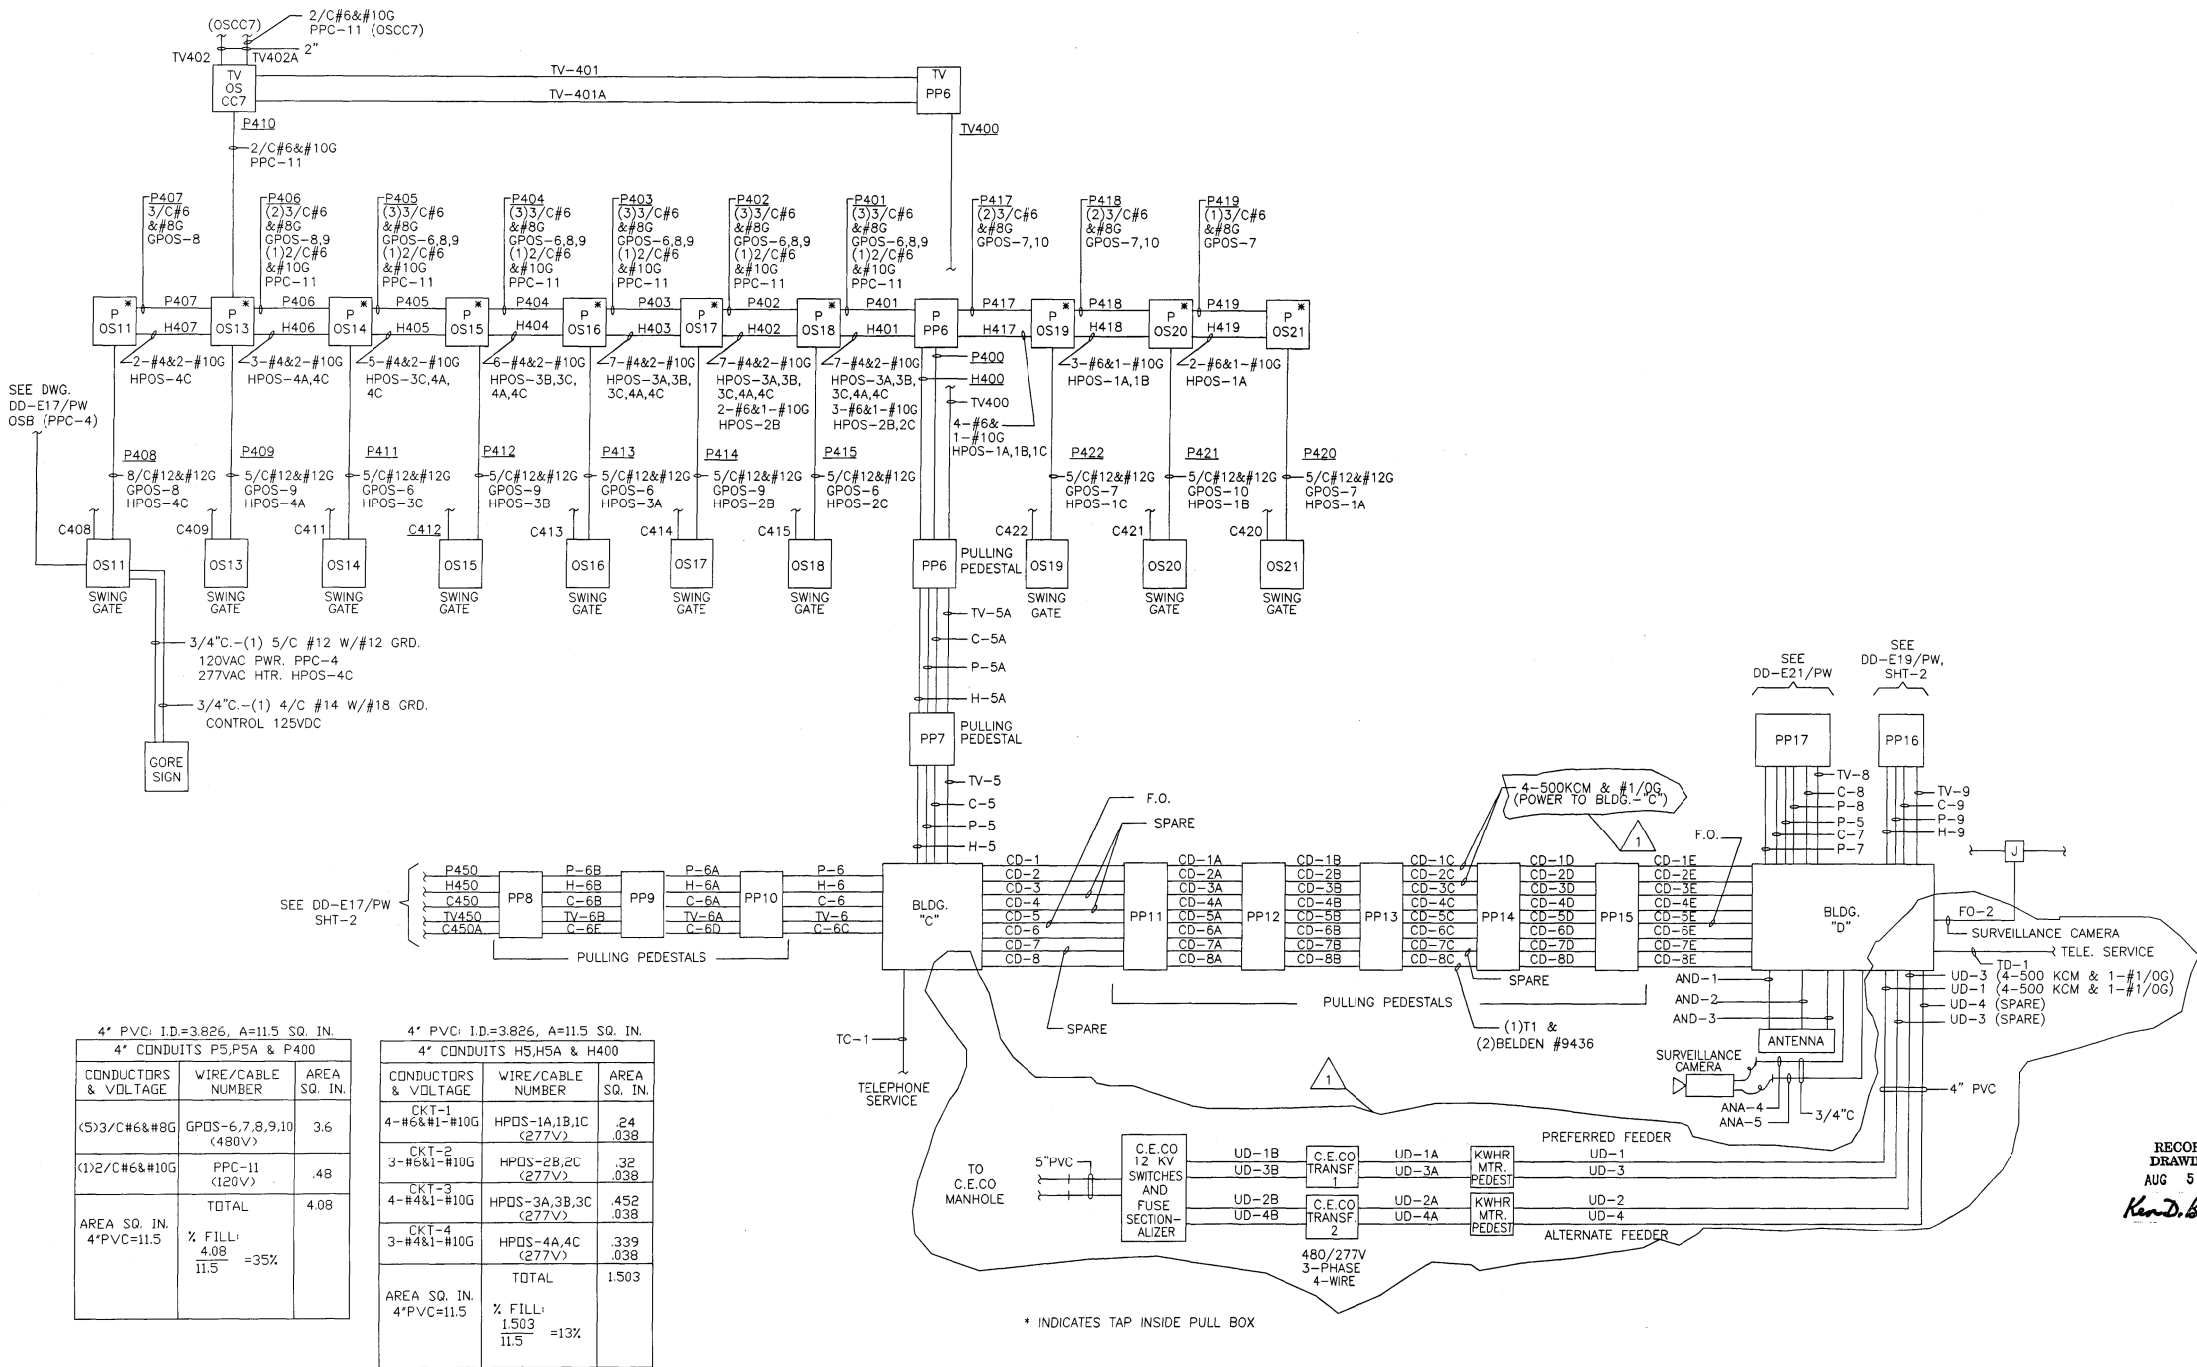

# NOTES:

- THE ABOVE DRAWINGS REPRESENT AS LET DESIGN TO AID CONTRACTOR IN ASCERTAINING EXISTING CONDITIONS.
- CONTRACTOR SHALL CONTACT IDOT D1 TO REQUEST THE MOST UP TO DATE RECORD DRAWINGS AVAILABLE AT THE TIME OF LETTING.

FOR INFORMATION ONLY

**SINGH**  
SINGH - ASSOCIATES INC.  
CONSULTING ENGINEERS

USER NAME = mgarvida  
FILE NAME = 126.D160T93-sht-details067  
PLOT SCALE = 2.000000:1.000000  
PLOT DATE = 06-MAY-2015 15:38

DESIGNED - DJ/AG  
DRAWN - DS/AS  
CHECKED - 1Y  
DATE - 5/6/2015

REVISED -  
REVISED -  
REVISED -  
REVISED -

STATE OF ILLINOIS  
DEPARTMENT OF TRANSPORTATION

REMOTE BUILDING C AND D INBOUND SLIP RAMP  
POWER AND HEATER WIRING

SCALE: NTS SHEET OF SHEETS STA. TO STA.

F.A.I. RTE. 90/94 SECTION 2012-0521 COUNTY COOK TOTAL SHEETS 165 SHEET NO. 126  
CONTRACT NO. 60T93  
ILLINOIS FED. AID PROJECT






GENERAL NOTES

1. DESIGNATIONS IN PARENTHESES AT CONTROL CABLE INDICATIONS ARE FOR CABLE IDENTIFICATION PURPOSES.

2. STRANDED CONDUCTOR CABLE SHALL BE TERMINATED BY LUGS, CUP WASHERS, OR PRESSURE TYPE CONNECTORS. STRANDED CABLES SHALL NOT BE WRAPPED AROUND SCREW TYPE TERMINALS.

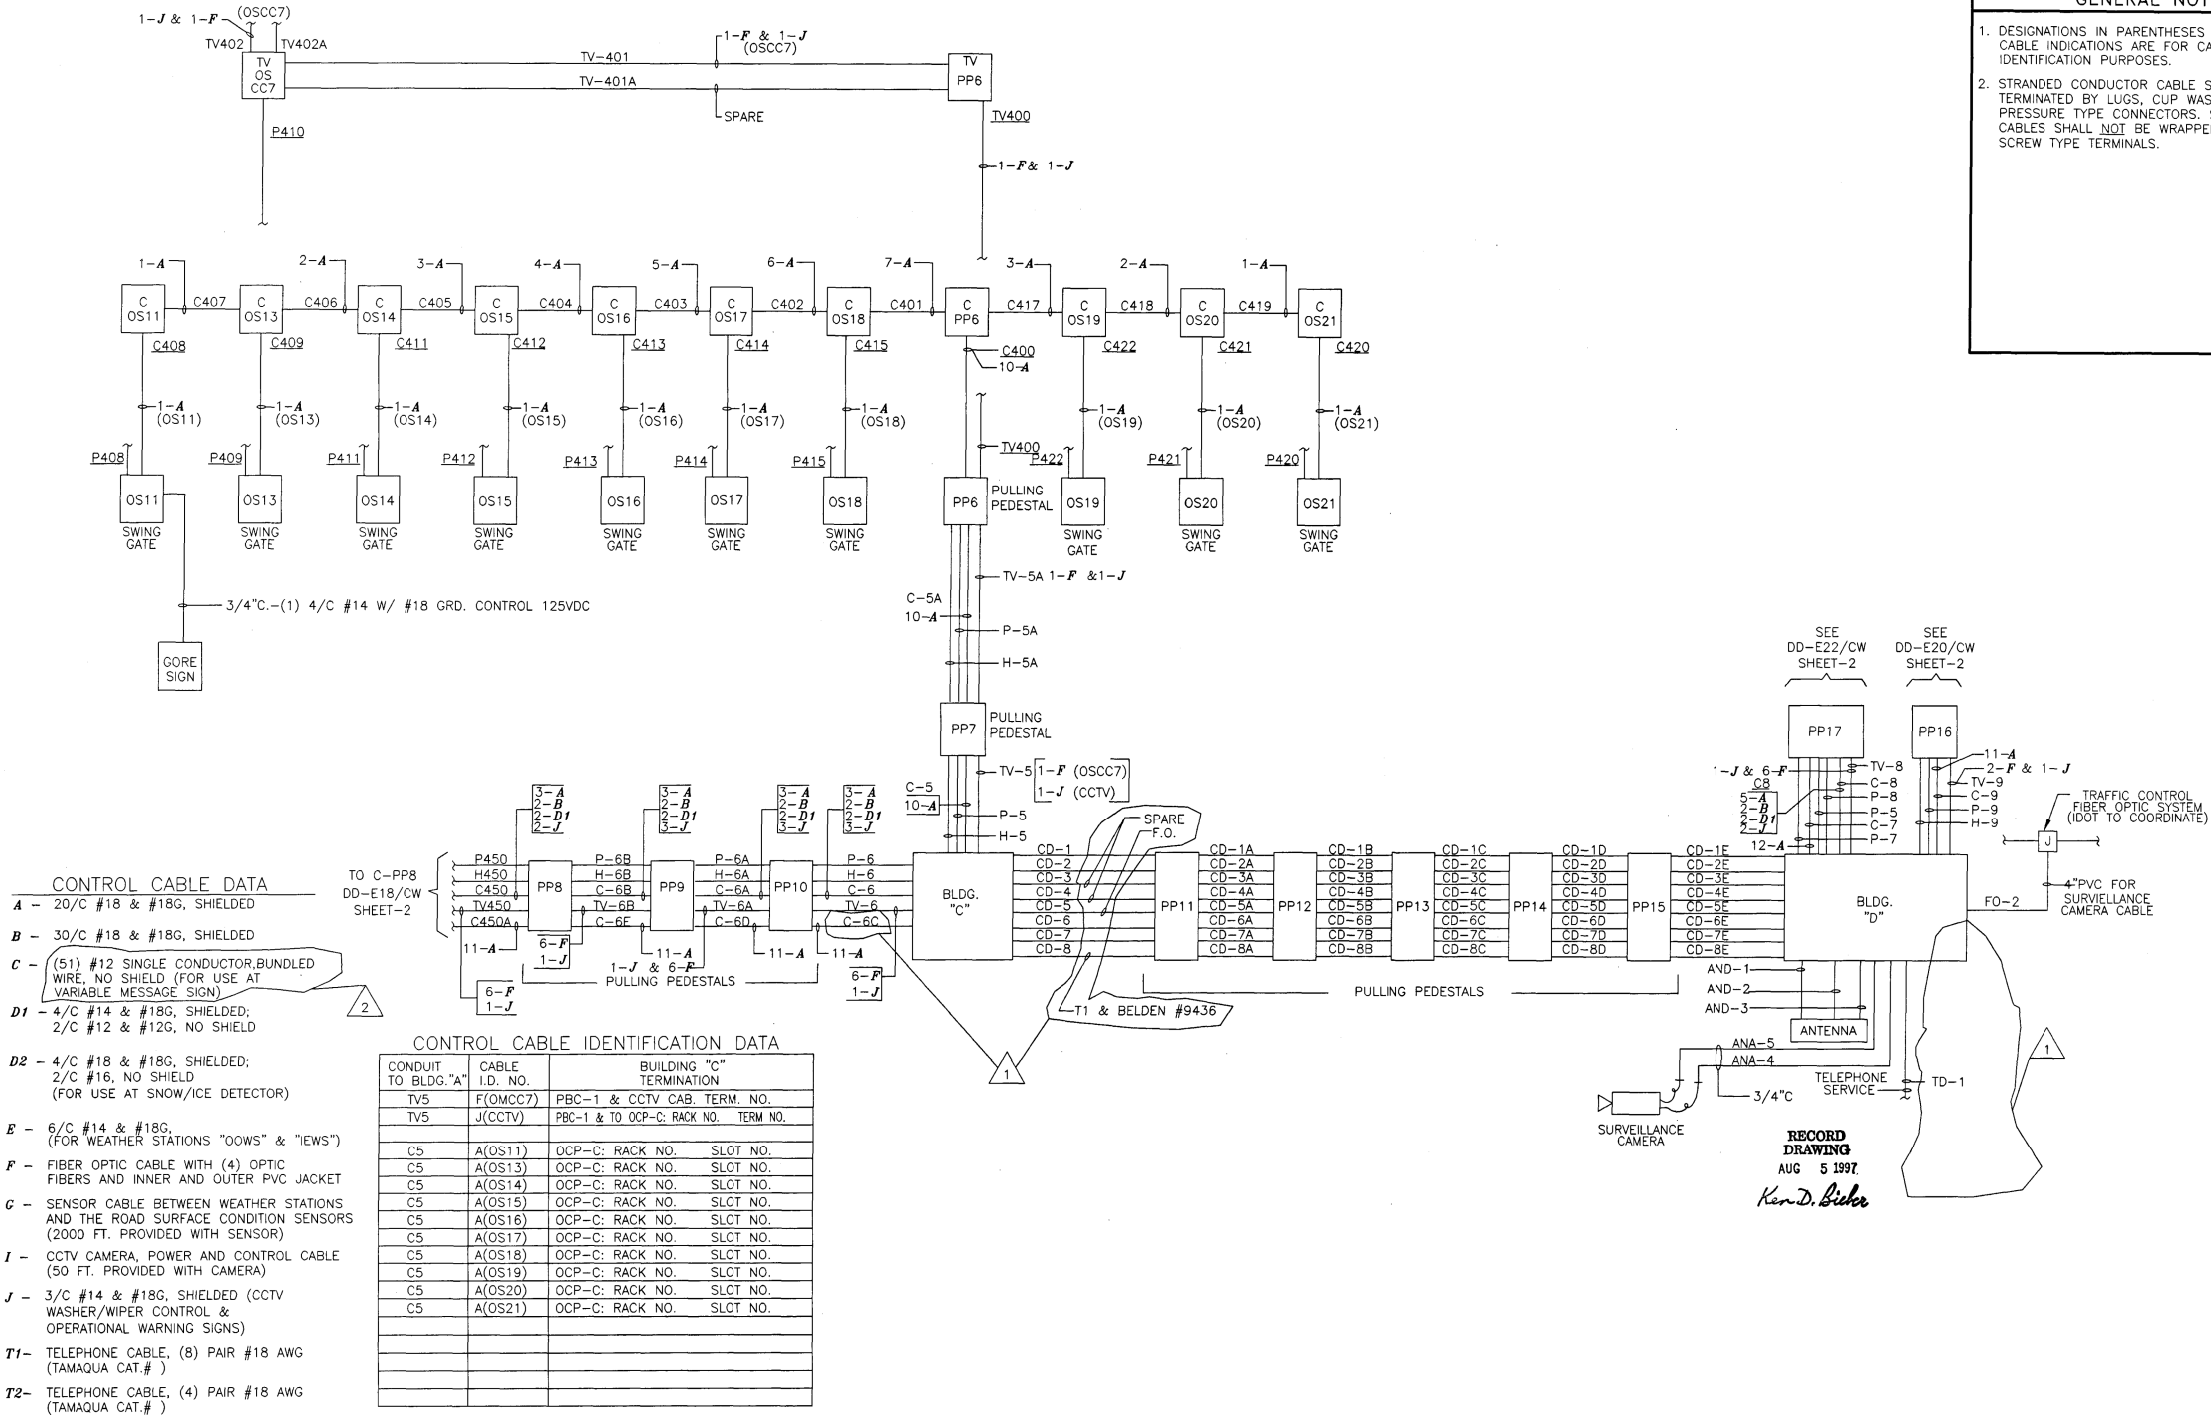

- NOTES:
- THE ABOVE DRAWINGS REPRESENT AS LET DESIGN TO AID CONTRACTOR IN ASCERTAINING EXISTING CONDITIONS.
  - CONTRACTOR SHALL CONTACT IDOT D1 TO REQUEST THE MOST UP TO DATE RECORD DRAWINGS AVAILABLE AT THE TIME OF LETTING.

FOR INFORMATION ONLY

J:\293\Task-2\CON\CADD\_Sheet\28.D160T93-sh1-details069.dgn

SINGH  
SINGH - ASSOCIATES INC.  
CONSULTING ENGINEERS

|                                        |                  |           |
|----------------------------------------|------------------|-----------|
| USER NAME = mgarvida                   | DESIGNED - DJ/AG | REVISED - |
| FILE NAME = 128.D160T93-sh1-details069 | DRAWN - DS/AS    | REVISED - |
| PLOT SCALE = 2.000000:1.000000         | CHECKED - 1Y     | REVISED - |
| PLOT DATE = 06-MAY-2015 15:40          | DATE - 5/6/2015  | REVISED - |

STATE OF ILLINOIS  
DEPARTMENT OF TRANSPORTATION

REMOTE BUILDING C AND D INBOUND SLIP RAMP  
CONTROL CABLE WIRING

SCALE: NTS SHEET OF SHEETS STA. TO STA.

|                           |           |        |              |           |
|---------------------------|-----------|--------|--------------|-----------|
| F.A.I. RTE.               | SECTION   | COUNTY | TOTAL SHEETS | SHEET NO. |
| 90/94                     | 2012-0521 | COOK   | 165          | 128       |
| CONTRACT NO. 60T93        |           |        |              |           |
| ILLINOIS FED. AID PROJECT |           |        |              |           |

J:\293\Task-2\CON\CADD\_Sheet\29-Die0193-sh1-details070.dgn

#### NOTES:

- THE ABOVE DRAWINGS REPRESENT AS LET DESIGN TO AID CONTRACTOR IN ASCERTAINING EXISTING CONDITIONS.
- CONTRACTOR SHALL CONTACT IDOT D1 TO REQUEST THE MOST UP TO DATE RECORD DRAWINGS AVAILABLE AT THE TIME OF LETTING.

**SINGH**  
CONSULTING ENGINEERS  
www.singhinc.com

|                                        |                  |           |
|----------------------------------------|------------------|-----------|
| USER NAME = mgarvada                   | DESIGNED - DJ/AG | REVISED - |
| FILE NAME = 129.D160T93-sh1-details070 | DRAWN - DS/AS    | REVISED - |
| PLOT SCALE = 2.000000:1.000000         | CHECKED - 1Y     | REVISED - |
| PLOT DATE = 06-MAY-2015 15:41          | DATE - 5/6/2015  | REVISED - |

|                  |           |
|------------------|-----------|
| DESIGNED - DJ/AG | REVISED - |
| DRAWN - DS/AS    | REVISED - |
| CHECKED - 1Y     | REVISED - |
| DATE - 5/6/2015  | REVISED - |

STATE OF ILLINOIS  
DEPARTMENT OF TRANSPORTATION


REMOTE BUILDING D INBOUND SLIP  
RAMP CONTROL CABLE WIRING


SCALE: NTS SHEET OF SHEETS STA. TO STA.

|                           |           |        |              |           |
|---------------------------|-----------|--------|--------------|-----------|
| F.A.I. RTE.               | SECTION   | COUNTY | TOTAL SHEETS | SHEET NO. |
| 90/94                     | 2012-0521 | COOK   | 165          | 129       |
| CONTRACT NO. 60T93        |           |        |              |           |
| ILLINOIS FED. AID PROJECT |           |        |              |           |

#### CONTROL CABLE IDENTIFICATION DATA

| CONDUIT TO BLDG. "D" | CABLE I.D. NO. | BUILDING "D" TERMINATION             |
|----------------------|----------------|--------------------------------------|
| TV8 & TV8A           | F(SCC1)        | PBD-1 & CCTV CAB. TERM. NO.          |
| TV8 & TV8A           | F(SCC2)        | PBD-1 & CCTV CAB. TERM. NO.          |
| TV8 & TV8A           | F(SCC3)        | PBD-1 & CCTV CAB. TERM. NO.          |
| TV8 & TV8A           | F(SCC4)        | PBD-1 & CCTV CAB. TERM. NO.          |
| TV8 & TV8A           | F(SCC5)        | PBD-1 & CCTV CAB. TERM. NO.          |
| TV8 & TV8A           | F(SCC6)        | PBD-1 & CCTV CAB. TERM. NO.          |
| TV8 & TV8A           | J(CCTV)        | PBD-1 & TO OCP-D: RACK NO. TERM. NO. |
| C8 & C8A             | A(IS10)        | OCP-D: RACK NO. SLOT NO.             |
| C8 & C8A             | A(IS11)        | OCP-D: RACK NO. SLOT NO.             |
| C8 & C8A             | A(IS12)        | OCP-D: RACK NO. SLOT NO.             |
| C8 & C8A             | A(IS13)        | OCP-D: RACK NO. SLOT NO.             |
| C8 & C8A             | A(IS14)        | OCP-D: RACK NO. SLOT NO.             |
| C8 & C8A             | B(ISSP1)       | OCP-D: RACK NO. SLOT NO.             |
| C8 & C8A             | B(ISSP2)       | OCP-D: RACK NO. SLOT NO.             |
| C8 & C8A             | J(ISSA1)       | OCP-D: RACK NO. SLOT NO.             |
| C8 & C8A             | J(ISSA2)       | OCP-D: RACK NO. SLOT NO.             |
| C8 & C8A             | D1(SIDD1-C)    | OCP-D: (TO SNOW/ICE DETECTOR PNL#1)  |
| C8 & C8A             | D1(SIDD2-C)    | OCP-D: (TO SNOW/ICE DETECTOR PNL#2)  |
| C7 & C7A             | A(ISRP1)       | OCP-D: RACK NO. SLOT NO.             |
| C7 & C7A             | A(IS1)         | OCP-D: RACK NO. SLOT NO.             |
| C7 & C7A             | A(IS2)         | OCP-D: RACK NO. SLOT NO.             |
| C7 & C7A             | A(ISRP2)       | OCP-D: RACK NO. SLOT NO.             |
| C7 & C7A             | A(IS3)         | OCP-D: RACK NO. SLOT NO.             |
| C7 & C7A             | A(IS4)         | OCP-D: RACK NO. SLOT NO.             |
| C7 & C7A             | A(IS5)         | OCP-D: RACK NO. SLOT NO.             |
| C7 & C7A             | A(IS6)         | OCP-D: RACK NO. SLOT NO.             |
| C7 & C7A             | A(IS7)         | OCP-D: RACK NO. SLOT NO.             |
| C7 & C7A             | A(IS8)         | OCP-D: RACK NO. SLOT NO.             |
| C7 & C7A             | A(IS9)         | OCP-D: RACK NO. SLOT NO.             |
| C7 & C7A             | A(ISB)         | OCP-D: RACK NO. SLOT NO.             |

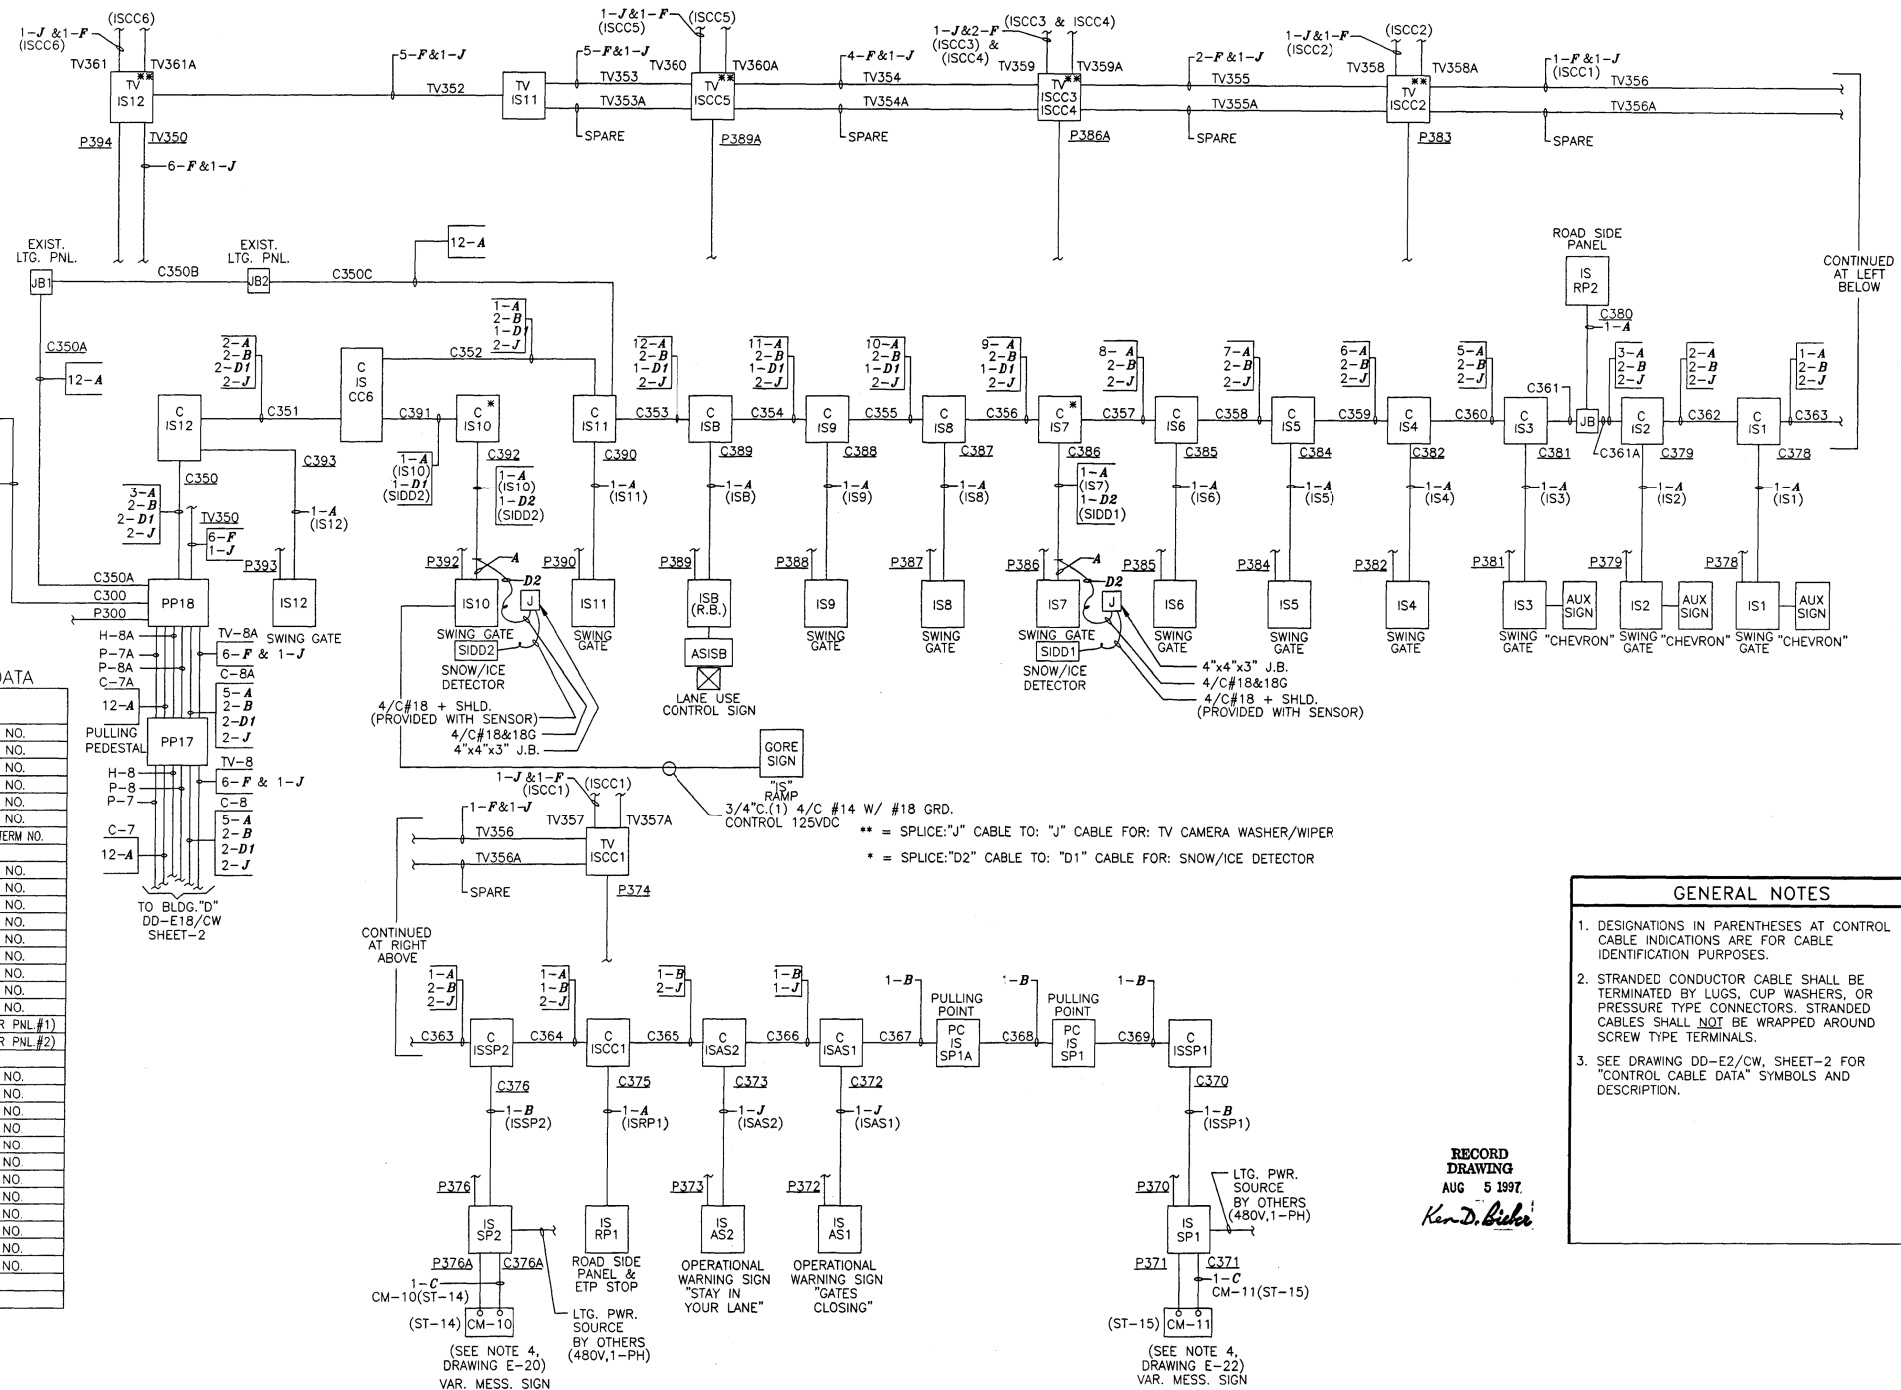


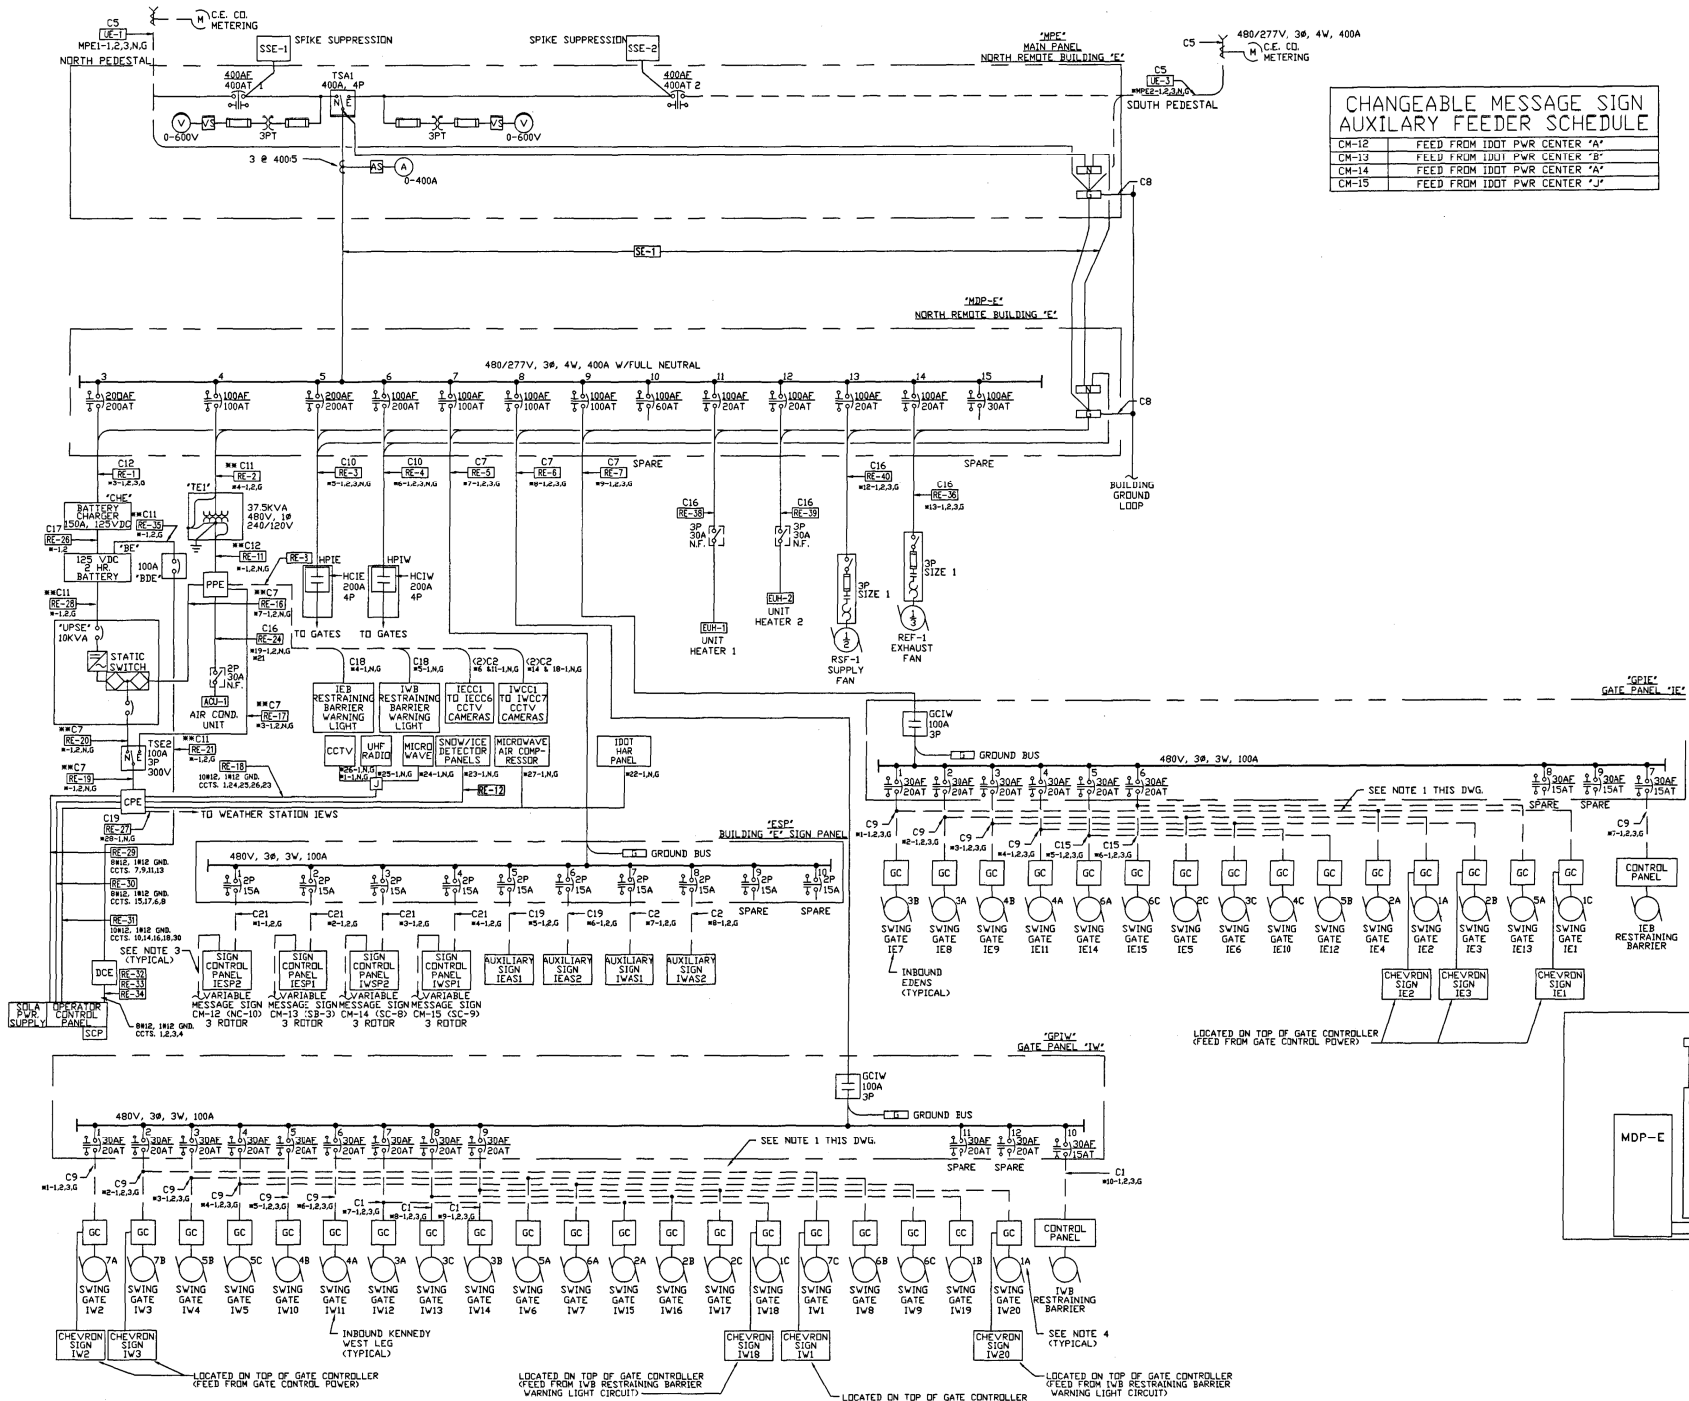

| CHANGEABLE MESSAGE SIGN<br>AUXILIARY FEEDER SCHEDULE |                               |  |
|------------------------------------------------------|-------------------------------|--|
| CM-12                                                | FEED FROM IDOT PWR CENTER 'A' |  |
| CM-13                                                | FEED FROM IDOT PWR CENTER 'B' |  |
| CM-14                                                | FEED FROM IDOT PWR CENTER 'A' |  |
| CM-15                                                | FEED FROM IDOT PWR CENTER 'J' |  |

| CABLE SCHEDULE |                                 |                 |
|----------------|---------------------------------|-----------------|
| TAG            | NO. & WIRE SIZE                 | REMARKS         |
| C1             | 3#6, 1#10 GND. 19# - 0021       | MULTI-CONDUCTOR |
| C2             | 2#6, 1#10 GND.                  |                 |
| C3             | 3#4, 1#6 GND.                   |                 |
| C4             | 2#10, 1#4 GND.                  |                 |
| C5             | 4#500CM, 1#10 GND.              |                 |
| C6             | 3#6, 1#6 GND.                   |                 |
| C7             | 3#2, 1#8 GND. 2#2, 1#8 GND.     |                 |
| C8             | 1#4/0 GROUND WIRE               |                 |
| C9             | 3#8, 1#10 GND.                  |                 |
| C10            | 4#3/0 1#6 GND.                  |                 |
| C11            | 2#2, 1#8 GND. 2#1, 1#8 GND.     |                 |
| C12            | 2#2/0 1#4 GND. 2#2, 1#4 GND.    |                 |
| C13            | 2 SETS OF 4#250CM, 1#2 GND. 2#4 |                 |
| C14            | 3#1, 1#6 GND.                   |                 |
| C15            | 3#10, 1#10 GND.                 |                 |
| C16            | 3#10, 1#12 GND.                 |                 |
| C17            | 2#4/0, 1#4 GND.                 |                 |
| C18            | 2#10, 1#10 GND.                 |                 |
| C19            | 2#8, 1#10 GND.                  |                 |
| C20            | 4#10, 1#10 GND.                 |                 |
| C21            | 2/C #4, 1#10 GND.               |                 |

- NOTES:
- POWER LINES TO INDIVIDUAL GATE CONTROLS TO BE PULLED THROUGH EXISTING 4" CONDUIT.
  - \* INDICATES PANEL PREFIX.
  - CIRCUIT FROM ROADWAY LIGHTING CONTROL, SEE CM SIGN SCHEDULE.
  - NUMBER SHOWN ADJACENT TO SWING GATE MOTOR IDENTIFIES CIRCUIT NUMBER OF THREE PHASE BREAKER IN RESPECTIVE GATE HEATER PANEL. LETTER INDICATES PHASE TO BE USED TO FEED THE 277V GATE HEATER. EXAMPLE: SWING GATE 1W20 IS FED FROM PANEL HPIW, CIRCUIT NUMBER ONE, PHASE A. SWING GATES 1W18 & 1W19 ARE FED FROM PHASE B AND PHASE C OF THE SAME CIRCUIT. SEE TYP. WIRING DIAGRAM ON DWG. E-89.

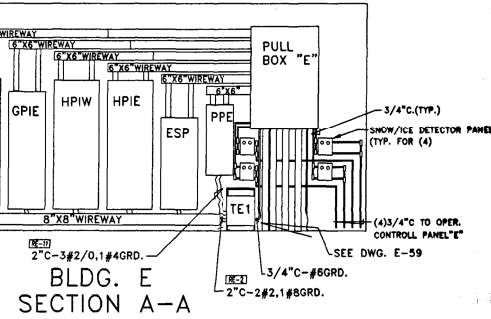

- NOTES:
- THE ABOVE DRAWINGS REPRESENT AS LET DESIGN TO AID CONTRACTOR IN ASCERTAINING EXISTING CONDITIONS.
  - CONTRACTOR SHALL CONTACT IDOT D1 TO REQUEST THE MOST UP TO DATE RECORD DRAWINGS AVAILABLE AT THE TIME OF LETTING.

FOR INFORMATION ONLY

J:\293\Task-2\CON\CADD\_Sheet\30\_Di0193-sh1-details01.dgn

**SINGH**  
CONSULTING ENGINEERS  
www.singhinc.com

USER NAME = mgarvada  
FILE NAME = 130\_Di0193-sh1-details01  
PLOT SCALE = 2.000000:1.000000  
PLOT DATE = 06-MAY-2015 15:42

DESIGNED - DJ/AG  
DRAWN - DS/AS  
CHECKED - 1Y  
DATE - 5/6/2015


REVISED -  
REVISED -  
REVISED -  
REVISED -

STATE OF ILLINOIS  
DEPARTMENT OF TRANSPORTATION


REMOTE BUILDING E SINGLE LINE DIAGRAM

SCALE: NTS SHEET OF SHEETS STA. TO STA.


|                           |           |        |              |           |
|---------------------------|-----------|--------|--------------|-----------|
| F.A.I. RTE.               | SECTION   | COUNTY | TOTAL SHEETS | SHEET NO. |
| 90/94                     | 2012-0521 | COOK   | 165          | 130       |
| CONTRACT NO. 60T93        |           |        |              |           |
| ILLINOIS FED. AID PROJECT |           |        |              |           |

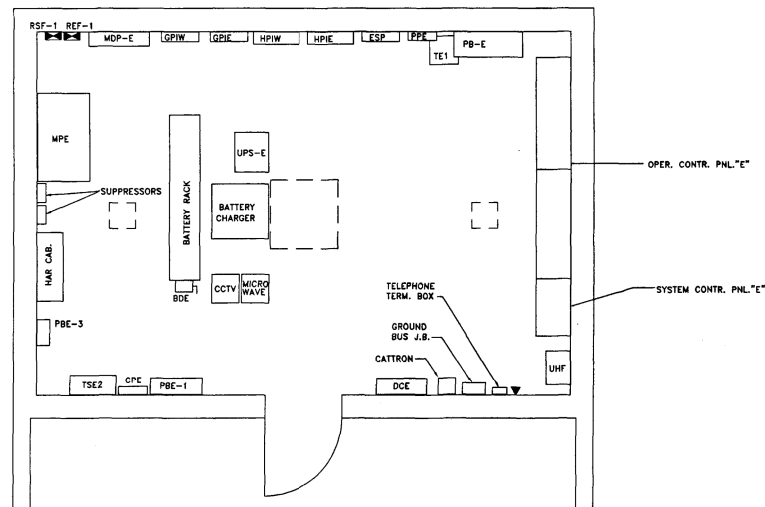

BLDG. E  
EQUIPMENT LAYOUT

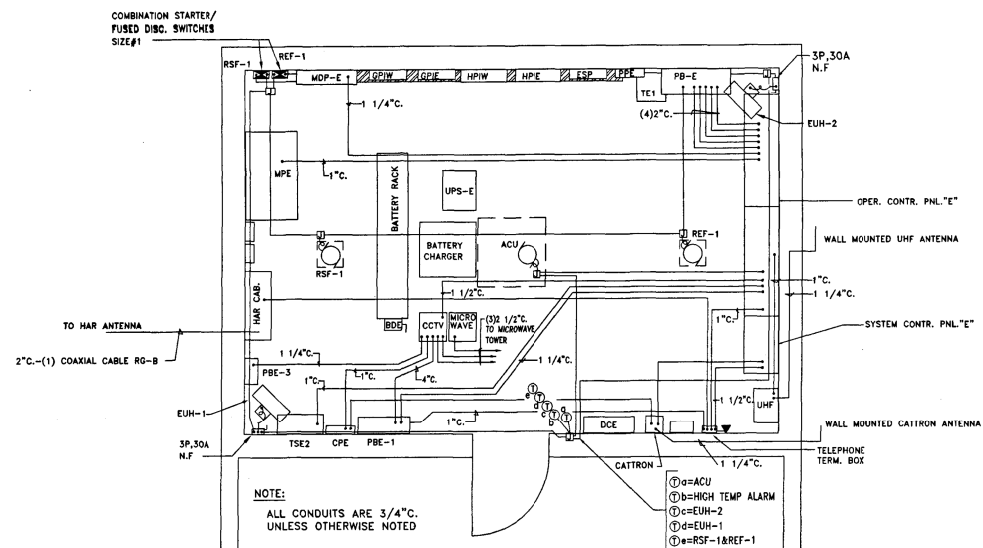

BLDG. E  
COMMUNICATIONS  
AND HVAC

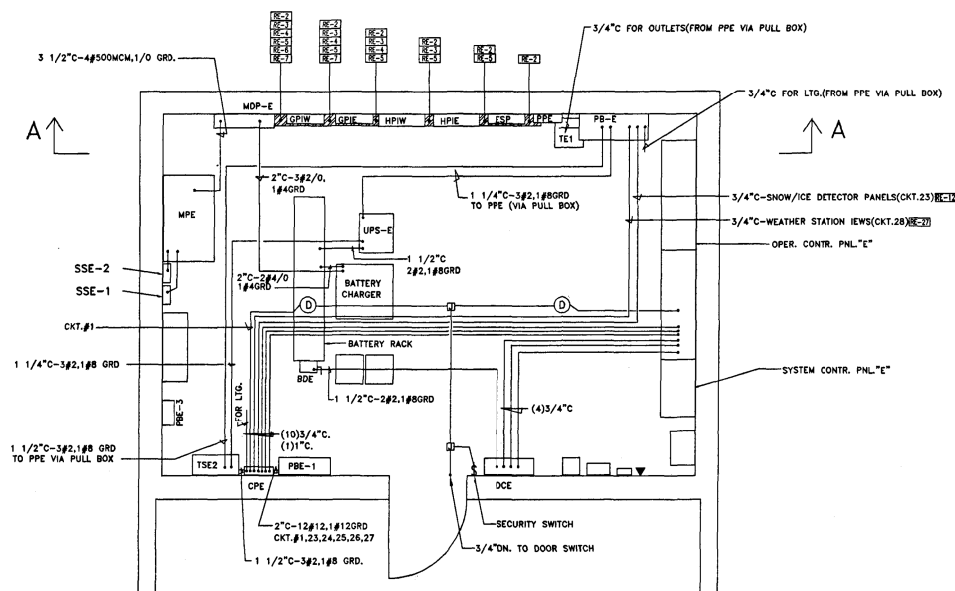

BLDG. E  
FEEDERS AND POWER

RECORD  
DRAWING  
AUG 5 1997  
*Kenn D. Bisher*

NOTES:

1. THE ABOVE DRAWINGS REPRESENT AS LET DESIGN TO AID CONTRACTOR IN ASCERTAINING EXISTING CONDITIONS.
2. CONTRACTOR SHALL CONTACT IDOT D1 TO REQUEST THE MOST UP TO DATE RECORD DRAWINGS AVAILABLE AT THE TIME OF LETTING.

FOR INFORMATION ONLY

**SINGH**  
CONSULTING ENGINEERS  
www.singhinc.com

|                                        |                  |           |
|----------------------------------------|------------------|-----------|
| USER NAME = mgarvada                   | DESIGNED - DJ/AG | REVISED - |
| FILE NAME = 131.D160T93-shd-details072 | DRAWN - DS/AS    | REVISED - |
| PLOT SCALE = 2.000000:1.000000         | CHECKED - 1Y     | REVISED - |
| PLOT DATE = 06-MAY-2015 15:43          | DATE - 5/6/2015  | REVISED - |

STATE OF ILLINOIS  
DEPARTMENT OF TRANSPORTATION

REMOTE BUILDING E EQUIPMENT LAYOUT


SCALE: NTS SHEET OF SHEETS STA. TO STA.

| F.A.I. RTE.               | SECTION   | COUNTY | TOTAL SHEETS | SHEET NO. |
|---------------------------|-----------|--------|--------------|-----------|
| 90/94                     | 2012-0521 | COOK   | 165          | 131       |
| CONTRACT NO. 60T93        |           |        |              |           |
| ILLINOIS FED. AID PROJECT |           |        |              |           |







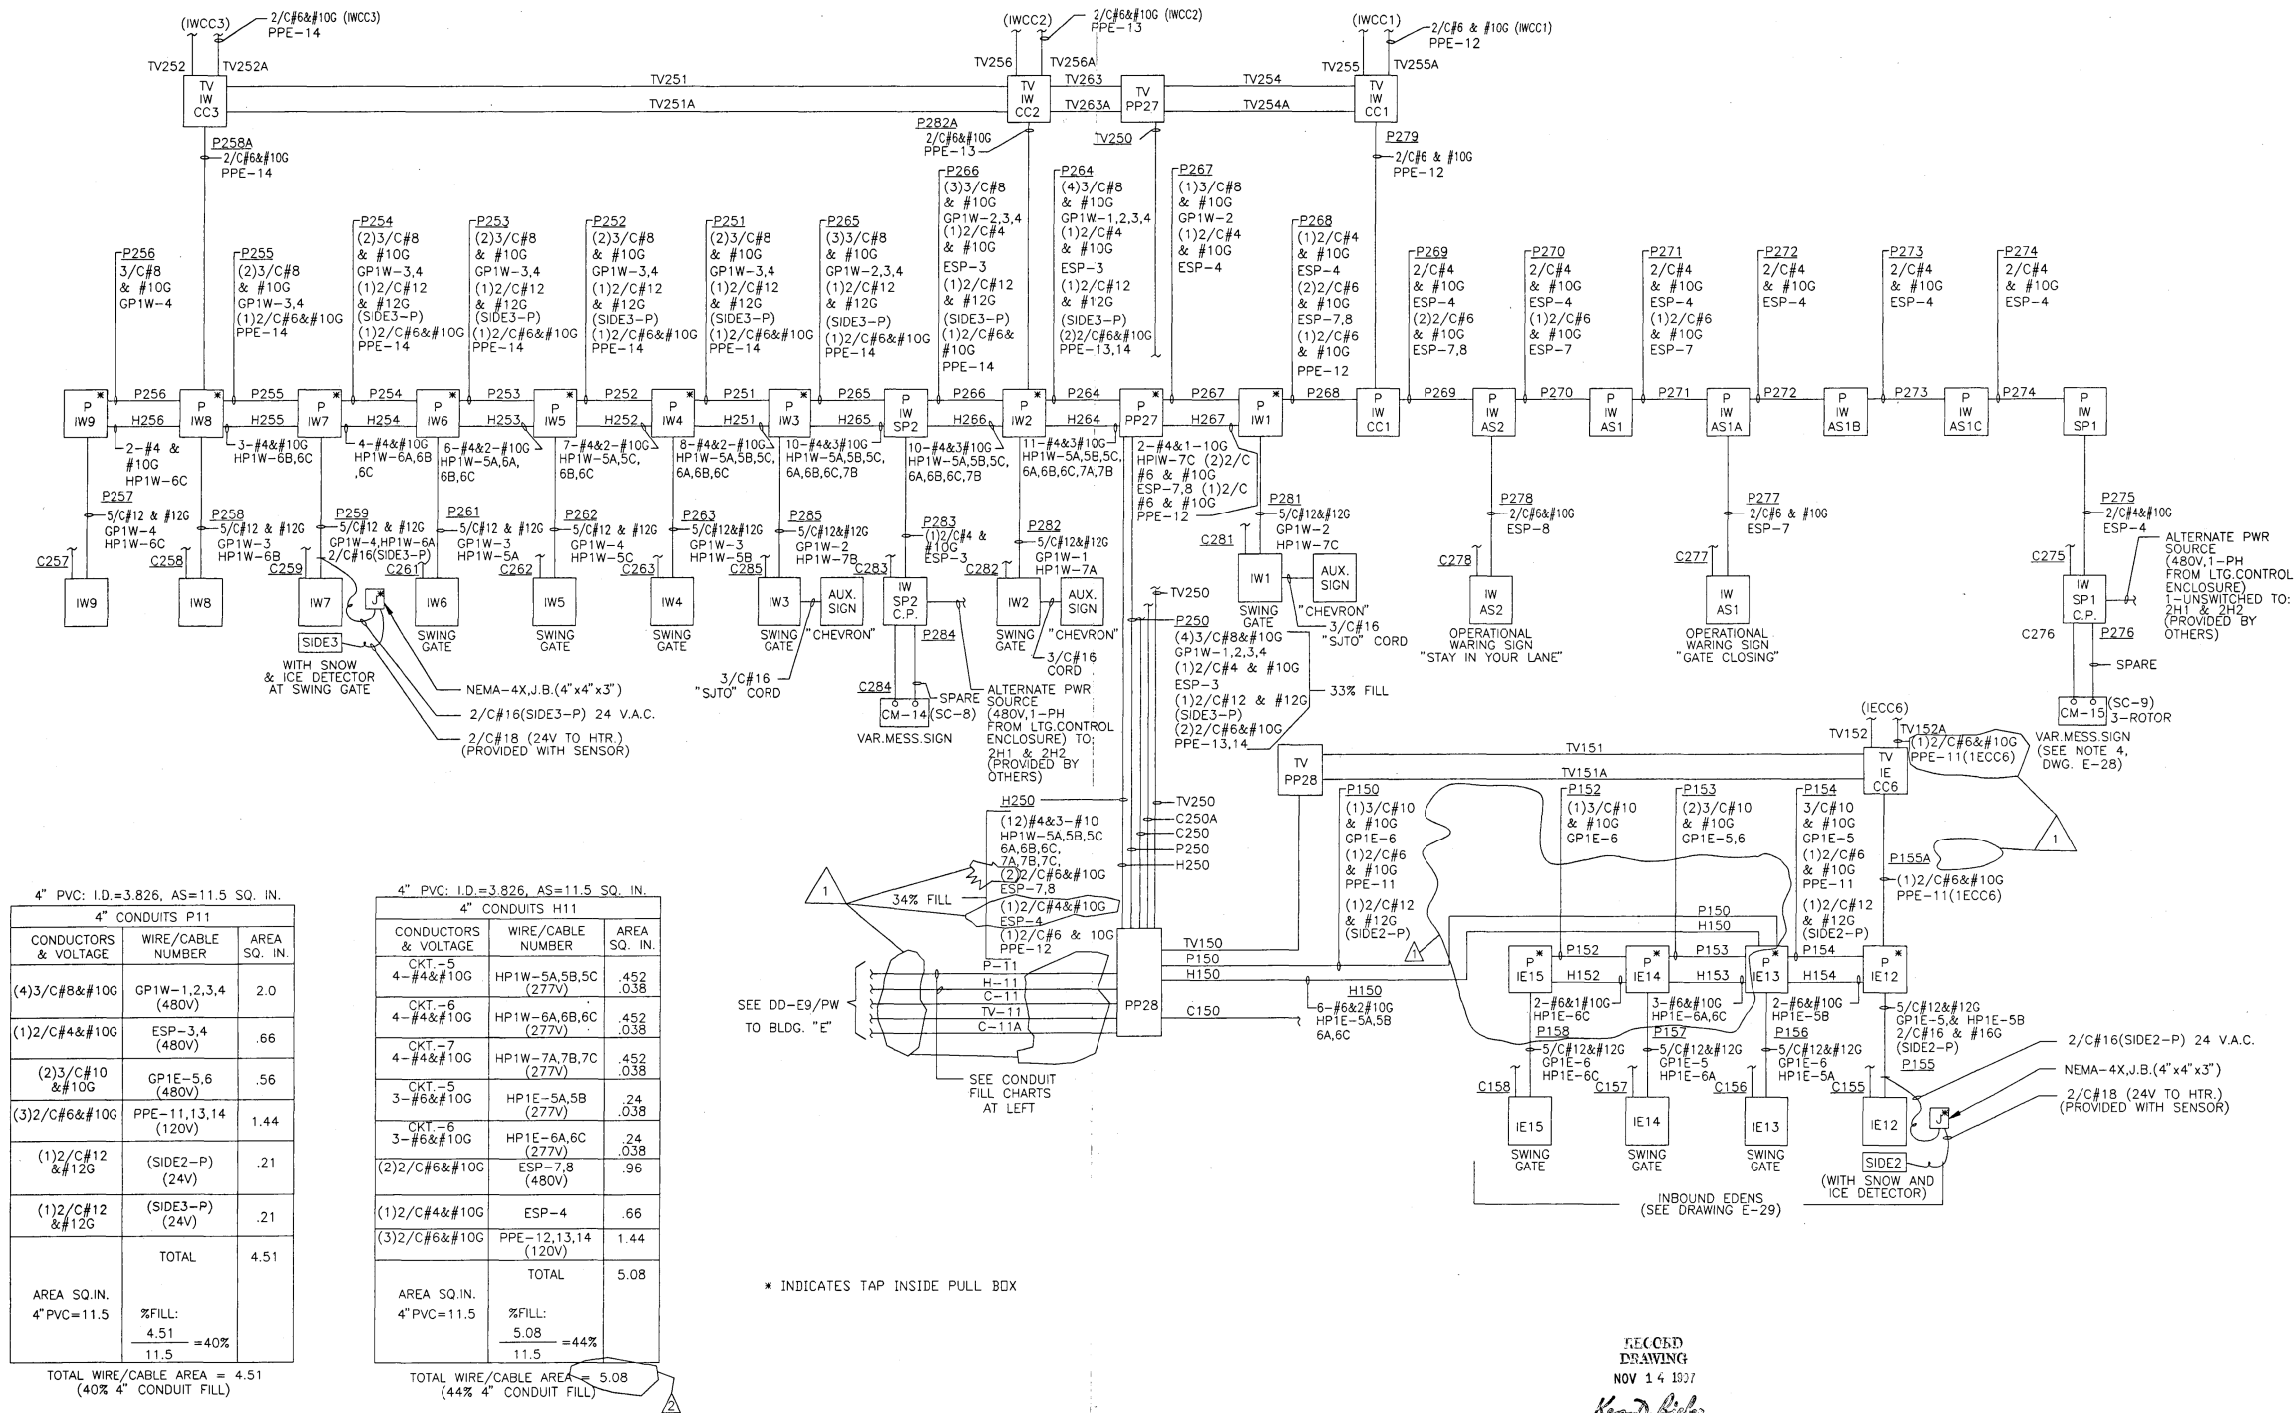

#### NOTES:

- THE ABOVE DRAWINGS REPRESENT AS LET DESIGN TO AID CONTRACTOR IN ASCERTAINING EXISTING CONDITIONS.
- CONTRACTOR SHALL CONTACT IDOT D1 TO REQUEST THE MOST UP TO DATE RECORD DRAWINGS AVAILABLE AT THE TIME OF LETTING.

**FOR INFORMATION ONLY**

**SINGH**  
CONSULTING ENGINEERS  
www.singhinc.com

USER NAME = mgarvada  
FILE NAME = 134.D160T93-sht-details075  
PLOT SCALE = 2.000000:1.000000  
PLOT DATE = 06-MAY-2015 15:45

DESIGNED - DJ/AG  
DRAWN - DS/AS  
CHECKED - 1Y  
DATE - 5/6/2015

REVISED -  
REVISED -  
REVISED -  
REVISED -


STATE OF ILLINOIS  
DEPARTMENT OF TRANSPORTATION

REMOTE BUILDING E KENNEDY AND INBOUND EDENS  
POWER AND HEATER WIRING

SCALE: NTS SHEET OF SHEETS STA. TO STA.

|                           |           |        |              |           |
|---------------------------|-----------|--------|--------------|-----------|
| F.A.I. RTE.               | SECTION   | COUNTY | TOTAL SHEETS | SHEET NO. |
| 90/94                     | 2012-0521 | COOK   | 165          | 134       |
| CONTRACT NO. 60T93        |           |        |              |           |
| ILLINOIS FED. AID PROJECT |           |        |              |           |



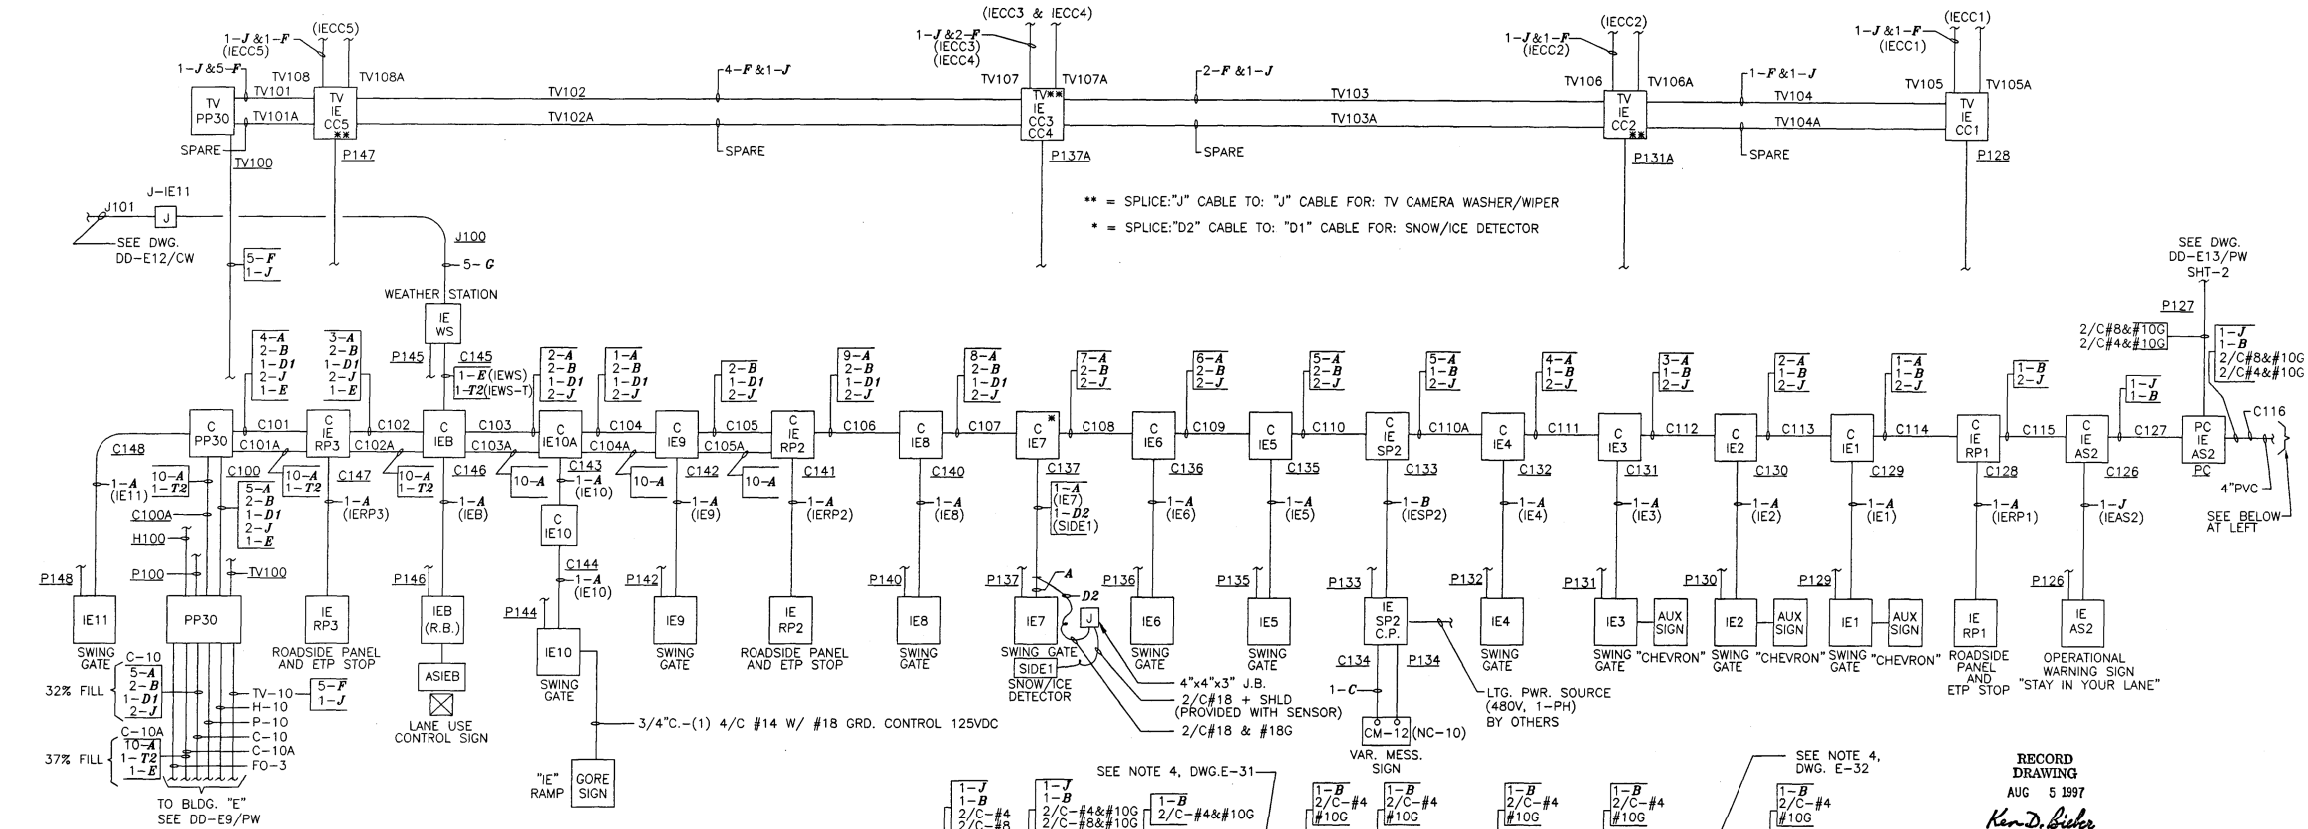

| CONTROL CABLE IDENTIFICATION DATA |                |                                     |  |
|-----------------------------------|----------------|-------------------------------------|--|
| CONDUIT TO BLDG. "E"              | CABLE I.D. NO. | BUILDING "E" TERMINATION            |  |
| TV-10                             | F(IECC1)       | PBE-1 & CCTV CAB. TERM. NO.         |  |
| TV-10                             | F(IECC2)       | PBE-1 & CCTV CAB. TERM. NO.         |  |
| TV-10                             | F(IECC3)       | PBE-1 & CCTV CAB. TERM. NO.         |  |
| TV-10                             | F(IECC4)       | PBE-1 & CCTV CAB. TERM. NO.         |  |
| TV-10                             | F(IECC5)       | PBE-1 & CCTV CAB. TERM. NO.         |  |
| TV-10                             | J(CCTV)        | PBE-1 & TO OCP-E: RACK NO. TERM NO. |  |
| C-10                              | A(IE9)         | OCP-E: RACK NO. SLOT NO.            |  |
| C-10                              | A(IE10)        | OCP-E: RACK NO. SLOT NO.            |  |
| C-10                              | A(IEB)         | OCP-E: RACK NO. SLOT NO.            |  |
| C-10                              | A(IEP3)        | OCP-E: RACK NO. SLOT NO.            |  |
| C-10                              | A(IE11)        | OCP-E: RACK NO. SLOT NO.            |  |
| C-10                              | B(IESP1)       | OCP-E: RACK NO. SLOT NO.            |  |
| C-10                              | B(IESP2)       | OCP-E: RACK NO. SLOT NO.            |  |
| C-10                              | J(EAS1)        | OCP-E: RACK NO. SLOT NO.            |  |
| C-10                              | J(EAS2)        | OCP-E: RACK NO. SLOT NO.            |  |
| C-10                              | D1(SIDE1-C)    | OCP-E: (TO SNOW/ICE DETECTOR PNL#1) |  |
| C-10A                             | A(IEP1)        | OCP-E: RACK NO. SLOT NO.            |  |
| C-10A                             | A(IE1)         | OCP-E: RACK NO. SLOT NO.            |  |
| C-10A                             | A(IE2)         | OCP-E: RACK NO. SLOT NO.            |  |
| C-10A                             | A(IE3)         | OCP-E: RACK NO. SLOT NO.            |  |
| C-10A                             | A(IE4)         | OCP-E: RACK NO. SLOT NO.            |  |
| C-10A                             | A(IEP2)        | OCP-E: RACK NO. SLOT NO.            |  |
| C-10A                             | A(IE5)         | OCP-E: RACK NO. SLOT NO.            |  |
| C-10A                             | A(IE6)         | OCP-E: RACK NO. SLOT NO.            |  |
| C-10A                             | A(IE7)         | OCP-E: RACK NO. SLOT NO.            |  |
| C-10A                             | A(IE8)         | OCP-E: RACK NO. SLOT NO.            |  |
| C-10A                             | E(IEWS)        | OCP-E: RACK NO. SLOT NO.            |  |
| C-10A                             | T2(IEWS-T)     | OCP-E: (TO TEL. J.B. AND TTCE)      |  |

| CONTROL CABLE DATA |                                                                                                              |
|--------------------|--------------------------------------------------------------------------------------------------------------|
| A                  | 20/C #18 & #18G, SHIELDED                                                                                    |
| B                  | 30/C #18 & #18G, SHIELDED                                                                                    |
| C                  | (51) #12 SINGLE CONDUCTOR, BUNDLED WIRE, NO SHIELD (FOR USE AT VARIABLE MESSAGE SIGN)                        |
| D1                 | 4/C #14 & #18G, SHIELDED 2C#12 & #12G, NO SHIELD.                                                            |
| D2                 | 4/C #18 & #18G, SHIELDED; 2/C #18, NO SHIELD (FOR USE AT SNOW/ICE DETECTOR)                                  |
| E                  | 6/C #14 & #18G, (FOR WEATHER STATIONS "OOWS" & "IEWS")                                                       |
| F                  | FIBER OPTIC CABLE WITH (4) OPTIC FIBERS AND INNER AND OUTER PVC JACKET                                       |
| G                  | SENSOR CABLE BETWEEN WEATHER STATIONS AND THE ROAD SURFACE CONDITION SENSORS (2000 FT. PROVIDED WITH SENSOR) |
| I                  | CCTV CAMERA, POWER AND CONTROL CABLE (50 FT. PROVIDED WITH CAMERA)                                           |
| J                  | 3/C #14 & #18G, SHIELDED (CCTV WASHER/WIPER CONTROL & OPERATIONAL WARNING SIGNS)                             |
| T1                 | TELEPHONE CABLE, (8) PAIR #18 AWG (TAMAQUA CAT.#)                                                            |
| T2                 | TELEPHONE CABLE, (4) PAIR #18 AWG (TAMAQUA CAT.#)                                                            |

RECORD DRAWING  
 AUG 5 1997  
*Ken D. Fisher*

**GENERAL NOTES**

- DESIGNATIONS IN PARENTHESES AT CONTROL CABLE INDICATIONS ARE FOR CABLE IDENTIFICATION PURPOSES.
- STRANDED CONDUCTOR CABLE SHALL BE TERMINATED BY LUGS, CUP WASHERS, OR PRESSURE TYPE CONNECTORS. STRANDED CABLES SHALL NOT BE WRAPPED AROUND SCREW TYPE TERMINALS.

- NOTES:**
- THE ABOVE DRAWINGS REPRESENT AS LET DESIGN TO AID CONTRACTOR IN ASCERTAINING EXISTING CONDITIONS.
  - CONTRACTOR SHALL CONTACT IDOT D1 TO REQUEST THE MOST UP TO DATE RECORD DRAWINGS AVAILABLE AT THE TIME OF LETTING.

**FOR INFORMATION ONLY**

J:\293\Task-2\CON\CADD\_Sheet\35.Die0193-shi-details076.dgn

**SINGH**  
CONSULTING ENGINEERS  
www.singhinc.com

|                                        |                  |           |
|----------------------------------------|------------------|-----------|
| USER NAME = mgarvada                   | DESIGNED - DJ/AG | REVISED - |
| FILE NAME = 135.Die0193-shi-details076 | DRAWN - DS/AS    | REVISED - |
| PLOT SCALE = 2.000000:1.000000         | CHECKED - 1Y     | REVISED - |
| PLOT DATE = 06-MAY-2015 15:46          | DATE - 5/6/2015  | REVISED - |


STATE OF ILLINOIS  
DEPARTMENT OF TRANSPORTATION

REMOTE BUILDING E INBOUND EDENS CONTROL CABLE WIRING

SCALE: NTS SHEET OF SHEETS STA. TO STA.

| F.A.I. RTE.               | SECTION   | COUNTY | TOTAL SHEETS | SHEET NO. |
|---------------------------|-----------|--------|--------------|-----------|
| 90/94                     | 2012-0521 | COOK   | 165          | 135       |
| CONTRACT NO. 60T93        |           |        |              |           |
| ILLINOIS FED. AID PROJECT |           |        |              |           |



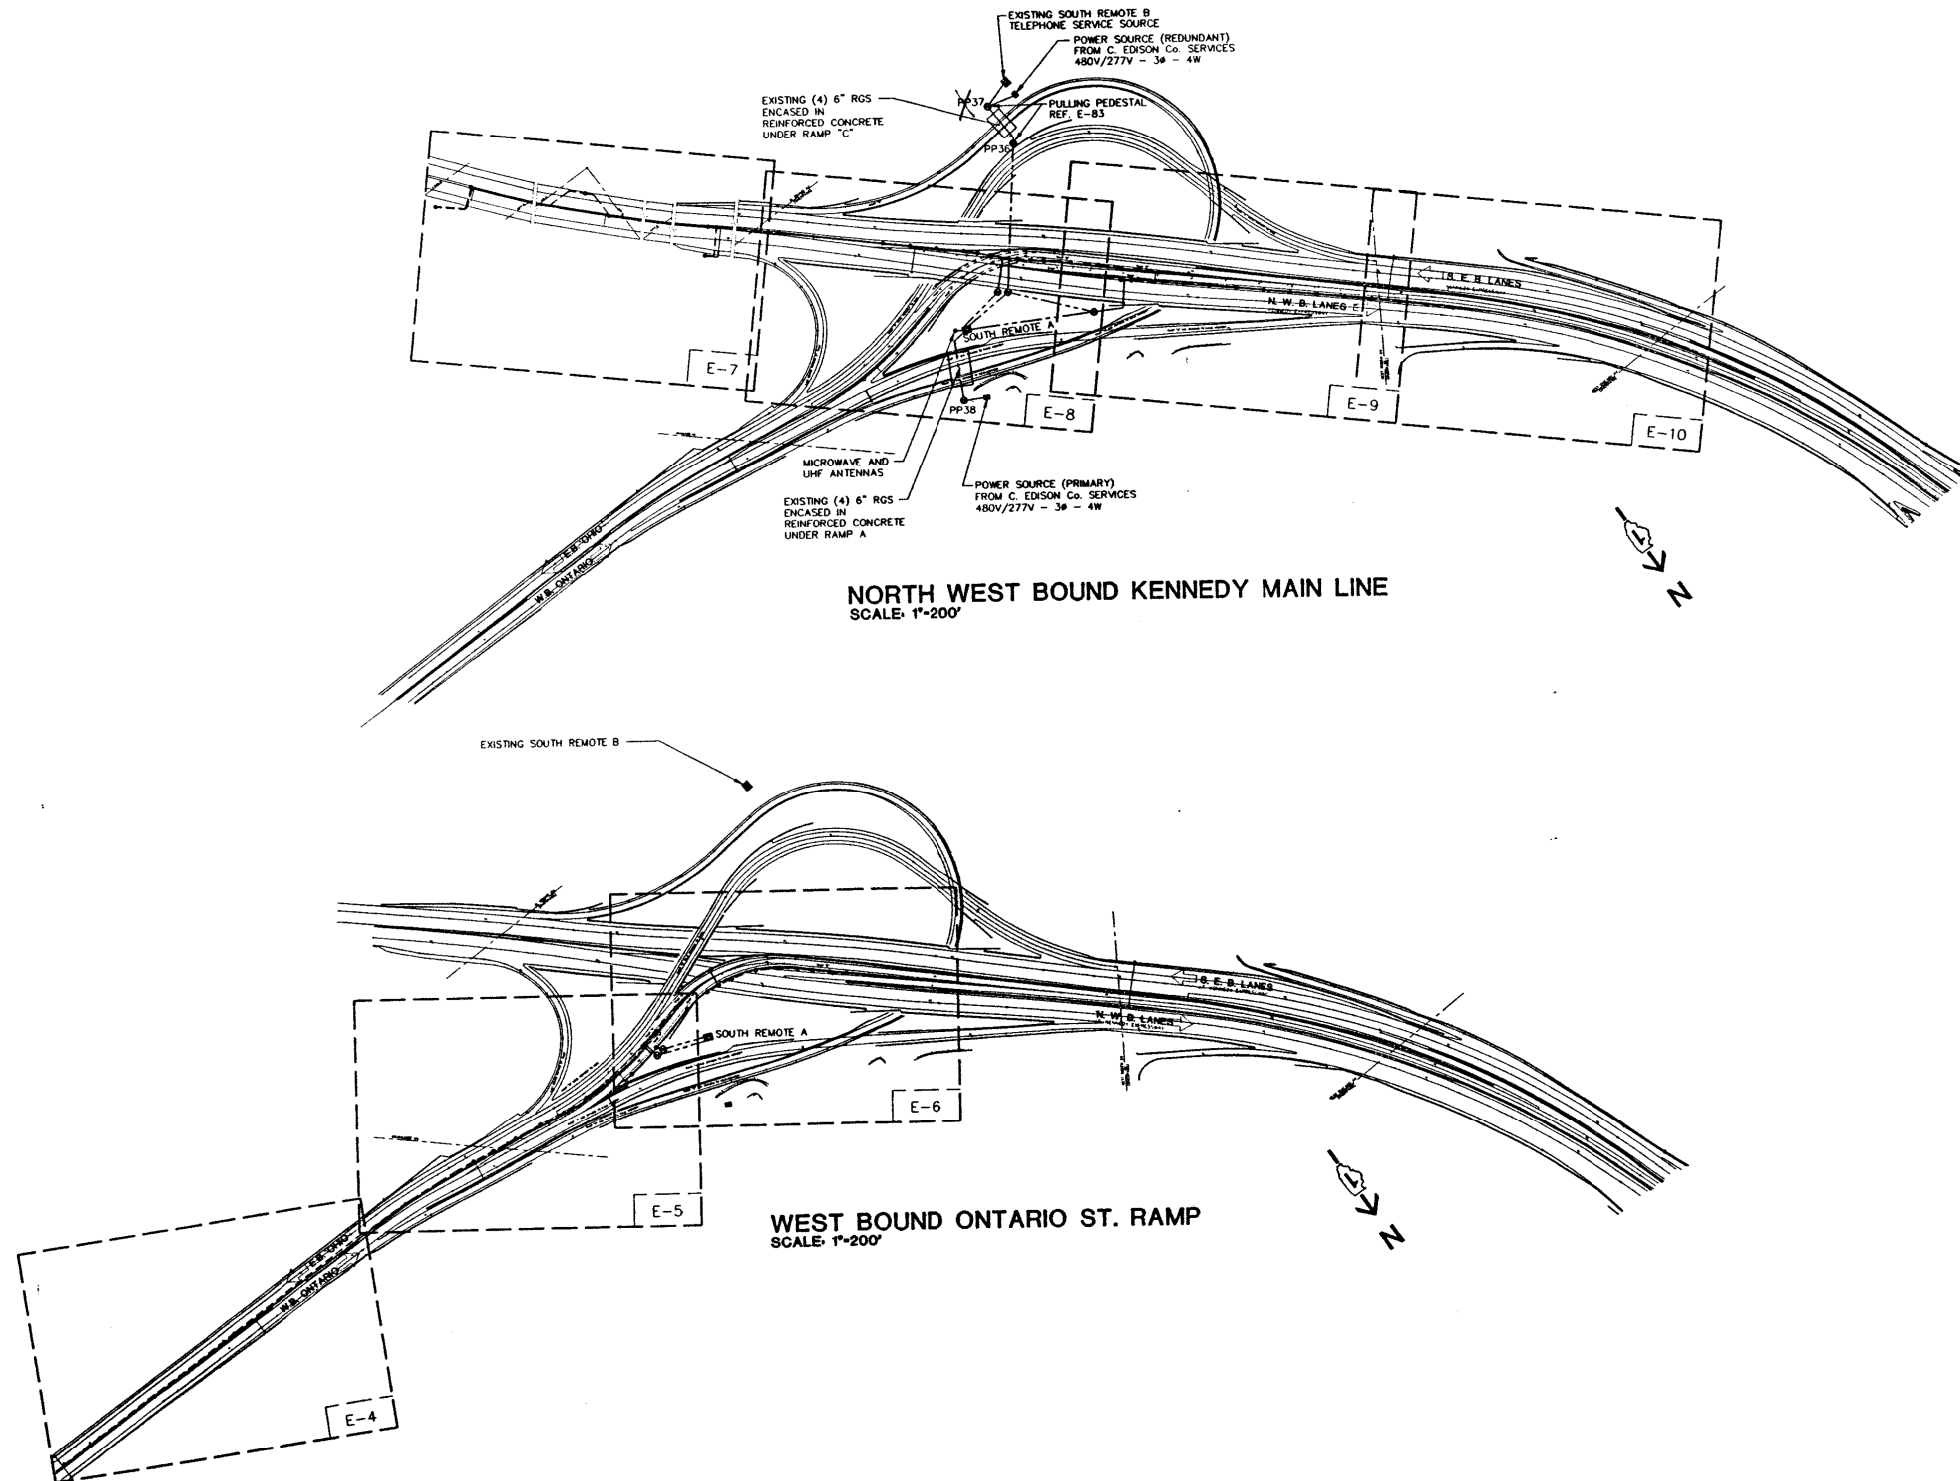

**NOTES:**

1. THE ABOVE DRAWINGS REPRESENT AS LET DESIGN TO AID CONTRACTOR IN ASCERTAINING EXISTING CONDITIONS.
2. CONTRACTOR SHALL CONTACT IDOT D1 TO REQUEST THE MOST UP TO DATE RECORD DRAWINGS AVAILABLE AT THE TIME OF LETTING.

**FOR INFORMATION ONLY**

J:\293\Task-2\CON\CADD\_Sheet\37\_D160T93-sh1-details078.dgn

**SINGH**  
CONSULTING ENGINEERS  
www.singhinc.com


|                                        |                  |           |
|----------------------------------------|------------------|-----------|
| USER NAME = mgarvido                   | DESIGNED - DJ/AG | REVISED - |
| FILE NAME = 137_D160T93-sh1-details078 | DRAWN - DS/AS    | REVISED - |
| PLOT SCALE = 2.000000:1.000000         | CHECKED - 1Y     | REVISED - |
| PLOT DATE = 06-MAY-2015 15:48          | DATE - 5/6/2015  | REVISED - |

**STATE OF ILLINOIS  
DEPARTMENT OF TRANSPORTATION**

**ONTARIO ST. AND N.W.B. KENNEDY ORIENTATION PLAN**



SCALE: NTS SHEET OF SHEETS STA. TO STA.

| F.A.I. RTE.               | SECTION   | COUNTY | TOTAL SHEETS | SHEET NO. |
|---------------------------|-----------|--------|--------------|-----------|
| 90/94                     | 2012-0521 | COOK   | 165          | 137       |
| CONTRACT NO. 60T93        |           |        |              |           |
| ILLINOIS FED. AID PROJECT |           |        |              |           |

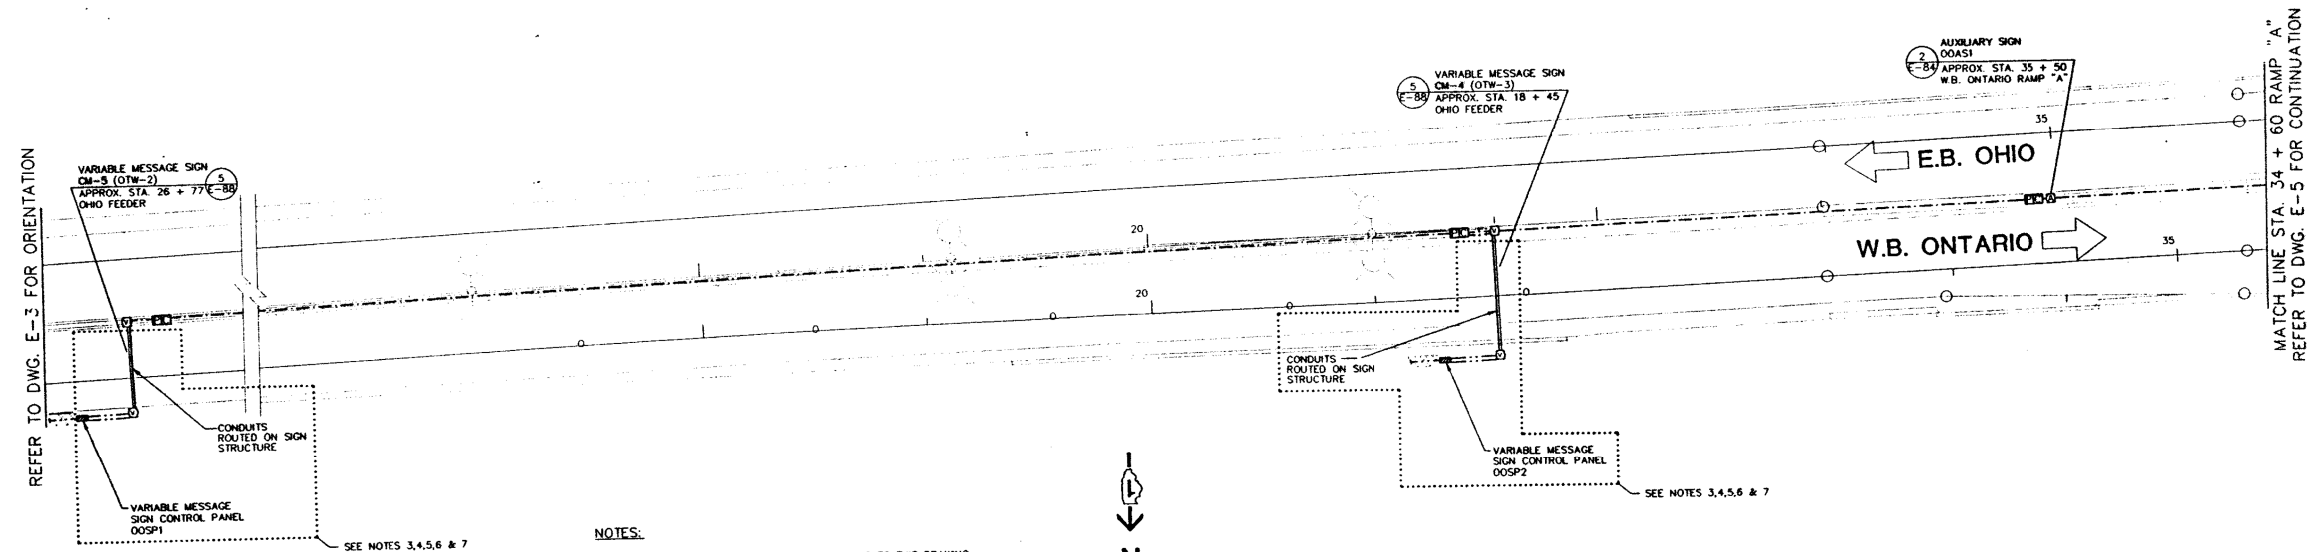

- 1) SEE DWG. E-2 FOR GENERAL NOTES PERTAINING TO THIS DRAWING.
- 2) CONDUIT & BOXES IN BARRIER WALL ARE EXISTING (INSTALLED UNDER REVCON CONTRACT).
- 3) PROVIDE PVC TO H.W. RIGID CONDUIT FITTINGS & ROUTE CONDUITS INSIDE THE VARIABLE SIGN TRUSS UP/ACROSS & DOWN THE SIGN.
- 4) PROVIDE H.W. RIGID CONDUIT TO PVC FITTING & ROUTE CONCRETE ENCASED PVC TO VARIABLE MESSAGE SIGN CONTROL PANEL. (SEE DETAIL ON DWG. E-88).
- 5) PROVIDE CONCRETE PAD, CONTROL PANEL CONDUITS & WIRES AS SHOWN. COORDINATE THE INSTALLATION OF THE LIGHTING CIRCUIT (BY OTHERS) INTO THE CONTROL PANEL. (SEE DWG. E-88 FOR LIGHTING CIRCUIT CONDUIT IN PAD).
- 6) UNLESS OTHERWISE INDICATED, PROVIDE ALL CABLE & WIRE FOR WORK SHOWN ON THIS SHEET, REGARDLESS OF THE CONTRACT UNDER WHICH THE RAGWAY WAS PROVIDED.
- 7) UNLESS OTHERWISE INDICATED, CONDUIT & BOXES NOT SHOWN WITHIN BOLL-BUT DASHED LINE IS EXISTING, OR WILL BE PROVIDED UNDER CONTRACT BY OTHERS.

**FOR INFORMATION ONLY**

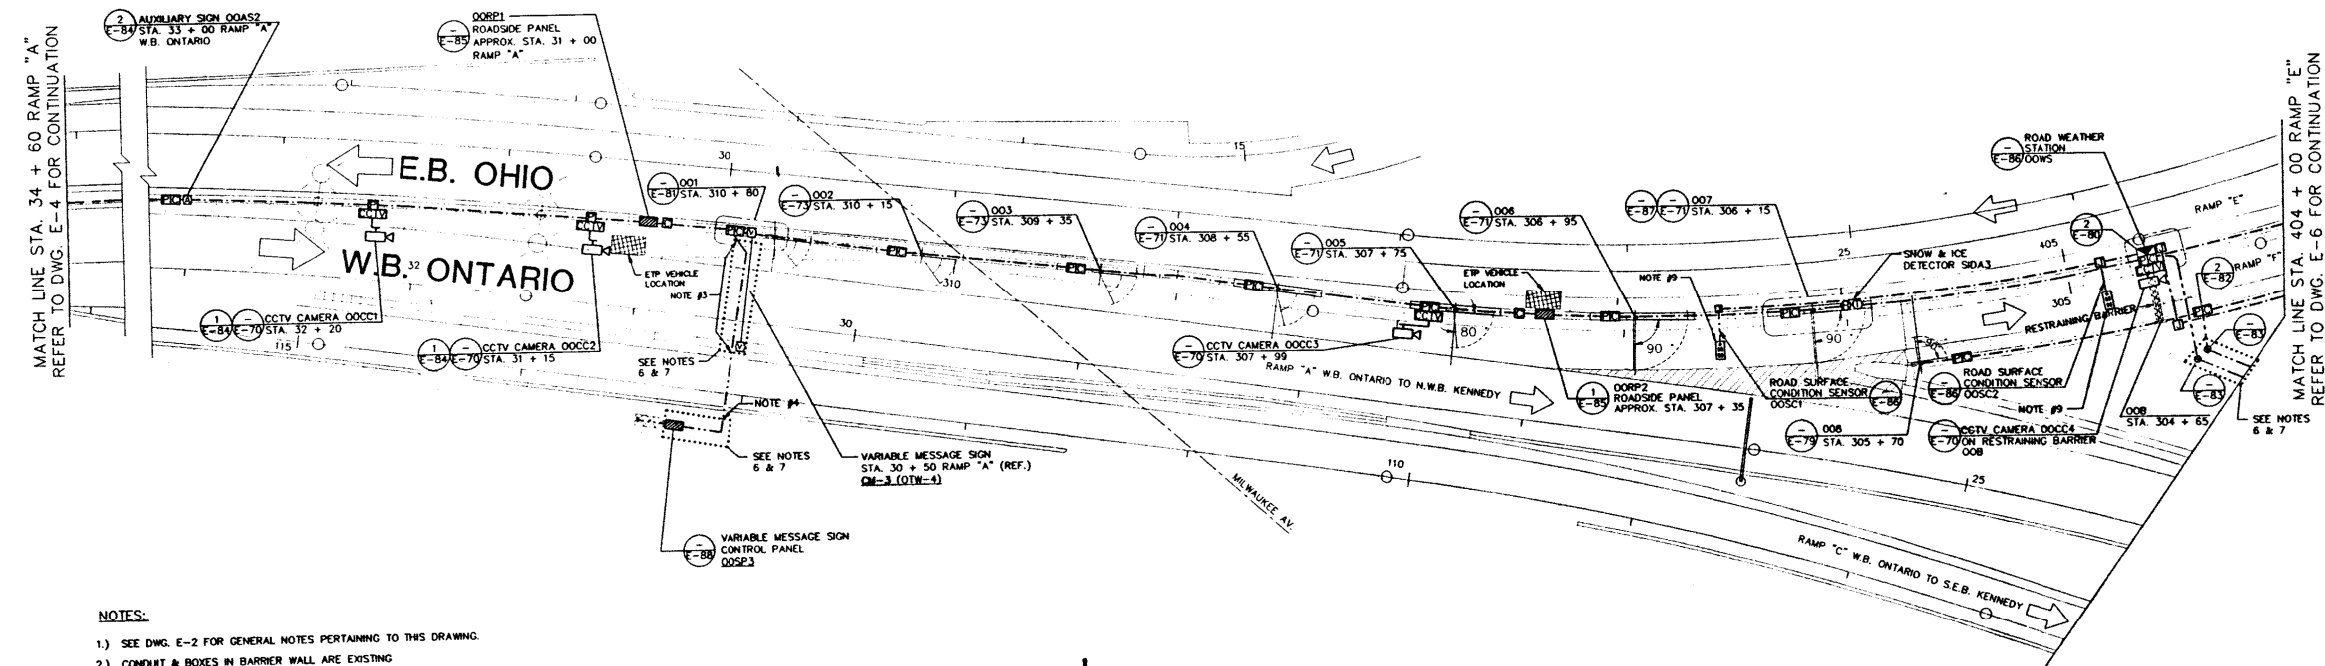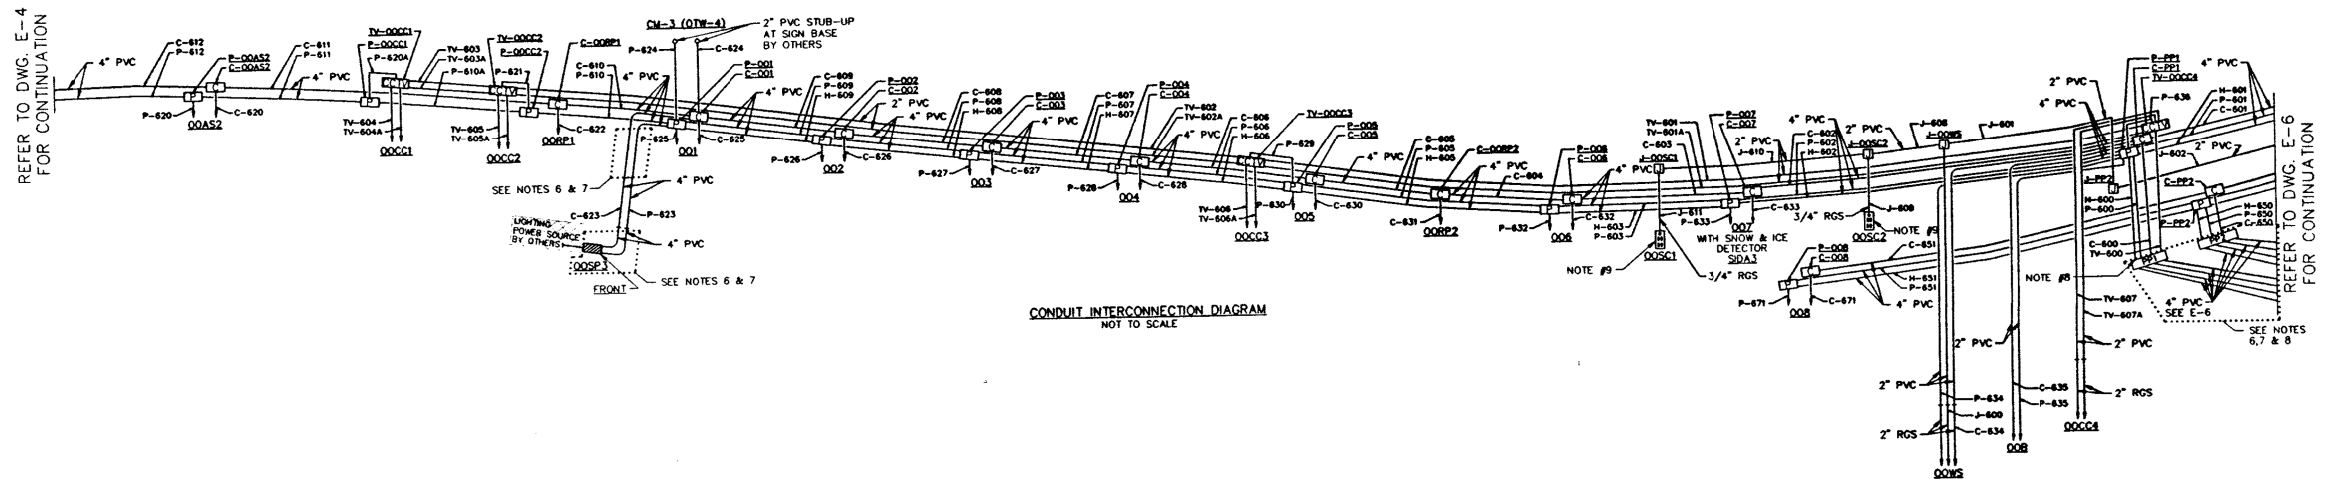

# NOTES:

- SEE DWG. E-2 FOR GENERAL NOTES PERTAINING TO THIS DRAWING.
- CONDUIT & BOXES IN BARRIER WALL ARE EXISTING (INSTALLED UNDER REVCON CONTRACT).
- LOCATE EXISTING 2"-4" PVC CONDUITS @ BOTH SIDES OF W.B. ONTARIO AND INSTALL NEW 2"-4" PVC BETWEEN THE POINTS.
- LOCATE EXISTING PVC CONDUITS, CONNECT 2"-4" PVC'S AND ROUTE CONCRETE ENCASED PVC TO VARIABLE MESSAGE SIGN CONTROL PANEL (SEE DETAIL ON DWG. E-88).
- PROVIDE CONCRETE PAD, CONTROL PANEL CONDUITS & WIRES AS SHOWN. COORDINATE THE INSTALLATION OF THE LIGHTING CIRCUIT (BY OTHERS) INTO THE CONTROL PANEL. (SEE DWG. E-88 FOR LIGHTING CIRCUIT CONDUIT IN PAD).
- UNLESS OTHERWISE INDICATED, PROVIDE ALL CABLE & WIRE FOR WORK SHOWN ON THIS SHEET, REGARDLESS OF THE CONTRACT UNDER WHICH THE RACENWAY IS PROVIDED.
- UNLESS OTHERWISE INDICATED, CONDUIT & BOXES NOT SHOWN WITHIN BOXED-OUT DASHED LINE IS EXISTING, OR WILL BE PROVIDED UNDER CONTRACT BY OTHERS.
- LOCATE EXISTING PVC CONDUITS, PROVIDE H.W. RIGID CONNECTORS AND INSTALL H.W. RIGID CONDUIT, PULL BOXES INCLUDING CONCRETE PADS (SEE DWG. E-83). PROVIDE NEW PVC CONCRETE ENCASED CONDUITS TO BUILDING "A" AS SHOWN.
- LOCATE PERMANENT SURVEY MARKER & UNCOVER ROADWAY TO LOCATE EXISTING SENSOR CONDUIT. INSTALL ROADWAY SENSOR AND CABLE AS SHOWN ON DWG. E-86.

## NOTES:

- THE ABOVE DRAWINGS REPRESENT AS LET DESIGN TO AID CONTRACTOR IN ASCERTAINING EXISTING CONDITIONS.
- CONTRACTOR SHALL CONTACT IDOT D1 TO REQUEST THE MOST UP TO DATE RECORD DRAWINGS AVAILABLE AT THE TIME OF LETTING.

**FOR INFORMATION ONLY**

**SINGH**  
CONSULTING ENGINEERS  
www.singhinc.com

USER NAME = mgarvada  
FILE NAME = 139\_D160T93-shd-details080  
PLOT SCALE = 2.000000:1.000000  
PLOT DATE = 06-MAY-2015 15:50

DESIGNED - DJ/AG  
DRAWN - DS/AS  
CHECKED - 1Y  
DATE - 5/6/2015


REVISED -  
REVISED -  
REVISED -  
REVISED -

STATE OF ILLINOIS  
DEPARTMENT OF TRANSPORTATION

W.B. ONTARIO /OHIO FEEDER POWER & CONTROL PLAN

SCALE: NTS SHEET OF SHEETS STA. TO STA.

|                           |           |        |              |           |
|---------------------------|-----------|--------|--------------|-----------|
| F.A.I. RTE.               | SECTION   | COUNTY | TOTAL SHEETS | SHEET NO. |
| 90/94                     | 2012-0521 | COOK   | 165          | 139       |
| CONTRACT NO. 60T93        |           |        |              |           |
| ILLINOIS FED. AID PROJECT |           |        |              |           |

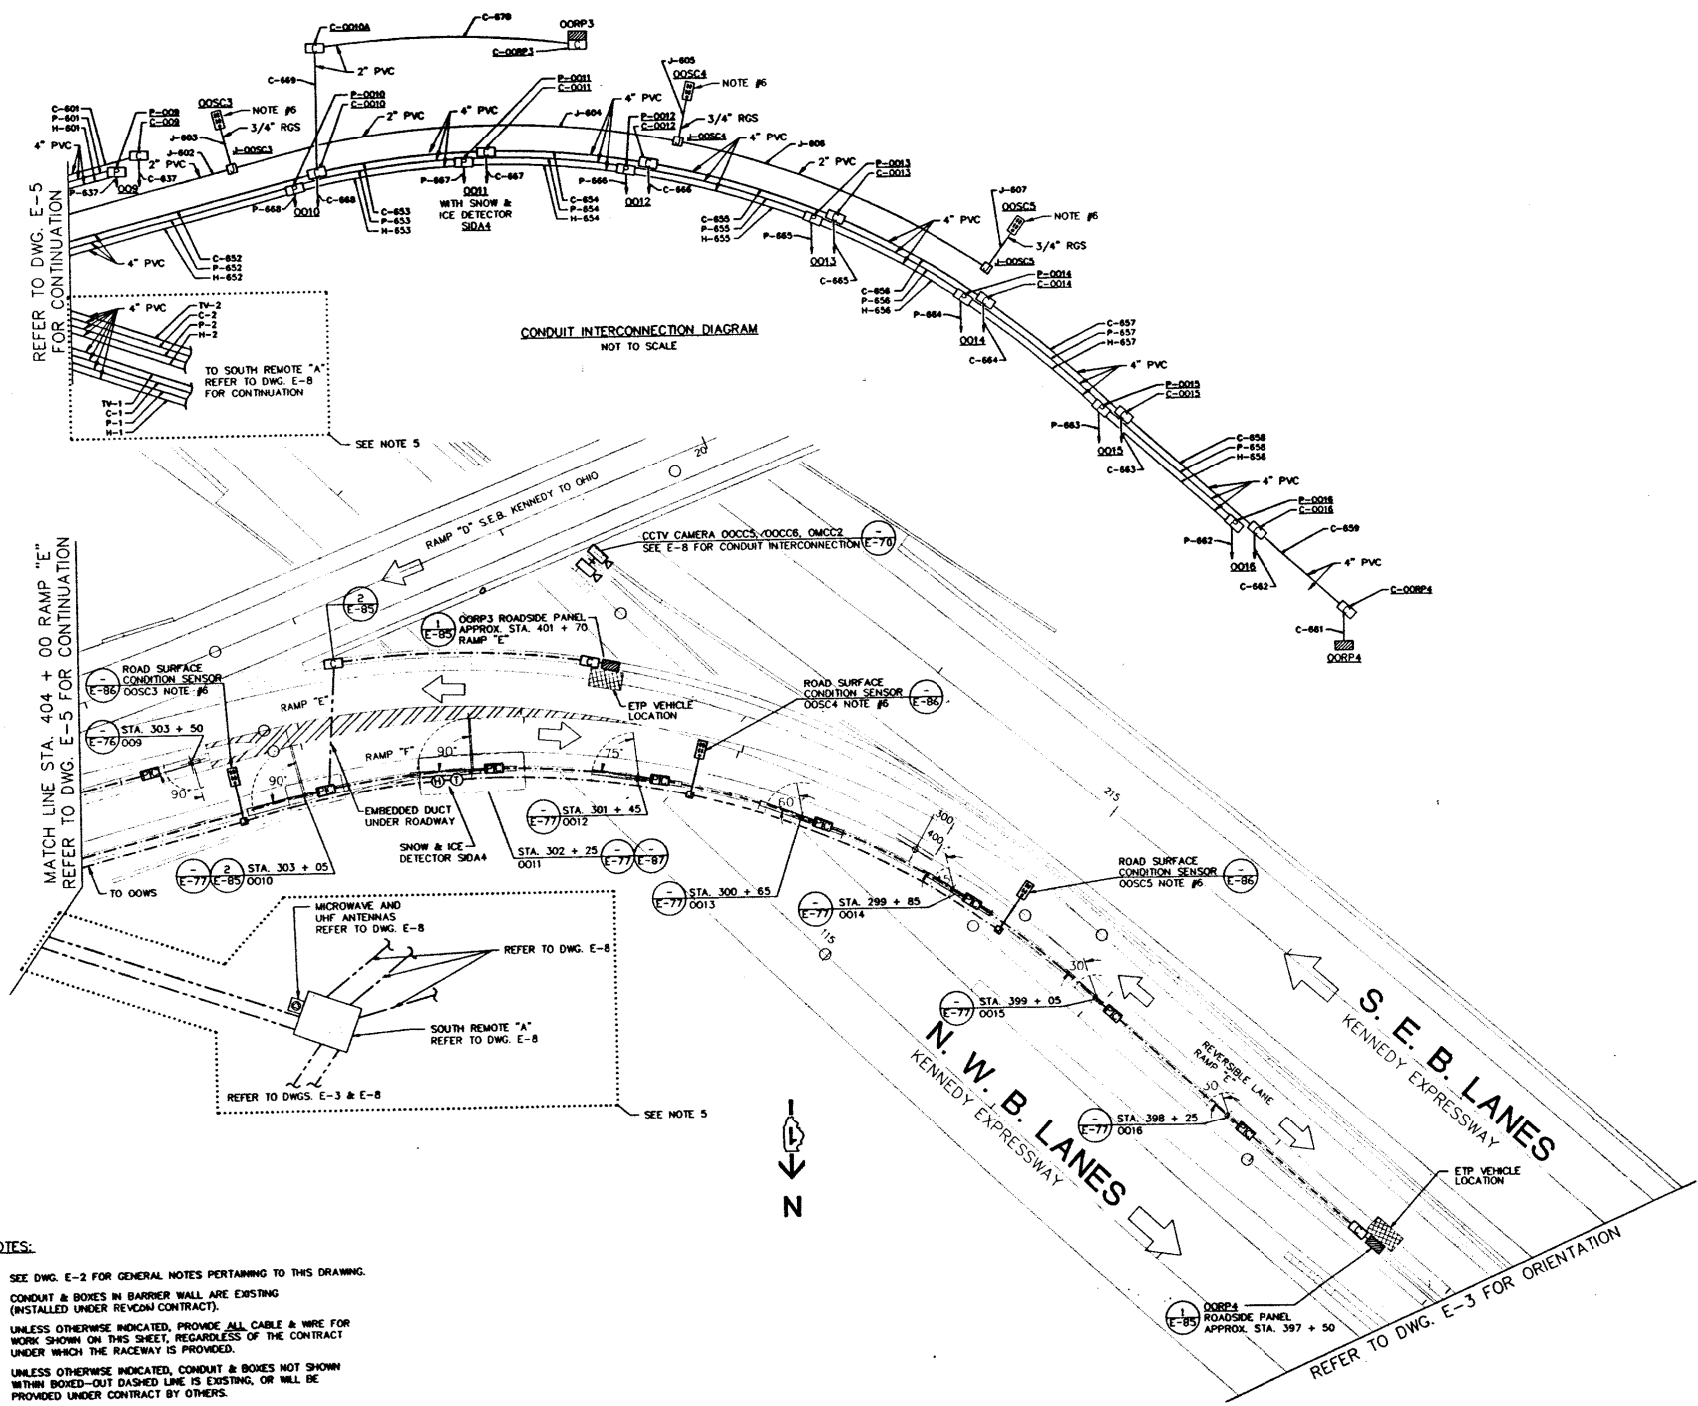

- NOTES:
- 1) SEE DWG. E-2 FOR GENERAL NOTES PERTAINING TO THIS DRAWING.
  - 2) CONDUIT & BOXES IN BARRIER WALL ARE EXISTING (INSTALLED UNDER REVCON CONTRACT).
  - 3) UNLESS OTHERWISE INDICATED, PROVIDE ALL CABLE & WIRE FOR WORK SHOWN ON THIS SHEET, REGARDLESS OF THE CONTRACT UNDER WHICH THE RACEWAY IS PROVIDED.
  - 4) UNLESS OTHERWISE INDICATED, CONDUIT & BOXES NOT SHOWN WITHIN BOXED-DASHED LINE IS EXISTING, OR WILL BE PROVIDED UNDER CONTRACT BY OTHERS.
  - 5) PROVIDE NEW PVC CONCRETE ENCASED CONDUITS TO BUILDING "A" AS SHOWN. SEE DWG. E-56 FOR BUILDING "A" INSTALLATION PLANS.
  - 6) LOCATE PERMANENT SURVEY MARKER & UNCOVER ROADWAY TO LOCATE EXISTING SENSOR CONDUIT. INSTALL ROADWAY SENSOR AND CABLE AS SHOWN ON DWG. E-88.

- NOTES:
1. THE ABOVE DRAWINGS REPRESENT AS LET DESIGN TO AID CONTRACTOR IN ASCERTAINING EXISTING CONDITIONS.
  2. CONTRACTOR SHALL CONTACT IDOT D1 TO REQUEST THE MOST UP TO DATE RECORD DRAWINGS AVAILABLE AT THE TIME OF LETTING.

FOR INFORMATION ONLY

J:\293\Task-2\CON\CADD\_Sheet\sv40.Dwg\0193-shd-details081.dgn

**SINGH**  
CONSULTING ENGINEERS  
www.singhinc.com

|                                        |                  |           |
|----------------------------------------|------------------|-----------|
| USER NAME = mgravido                   | DESIGNED - DJ/AG | REVISED - |
| FILE NAME = 140.D160T93-shd-details081 | DRAWN - DS/AS    | REVISED - |
| PLOT SCALE = 2.000000:1.000000         | CHECKED - 1Y     | REVISED - |
| PLOT DATE = 06-MAY-2015 15:51          | DATE - 5/6/2015  | REVISED - |

STATE OF ILLINOIS  
DEPARTMENT OF TRANSPORTATION


W.B. ONTARIO /OHIO FEEDER POWER & CONTROL PLAN

SCALE: NTS SHEET OF SHEETS STA. TO STA.

| F.A.I. RTE.               | SECTION   | COUNTY | TOTAL SHEETS | SHEET NO. |
|---------------------------|-----------|--------|--------------|-----------|
| 90/94                     | 2012-0521 | COOK   | 165          | 140       |
| CONTRACT NO. 60T93        |           |        |              |           |
| ILLINOIS FED. AID PROJECT |           |        |              |           |





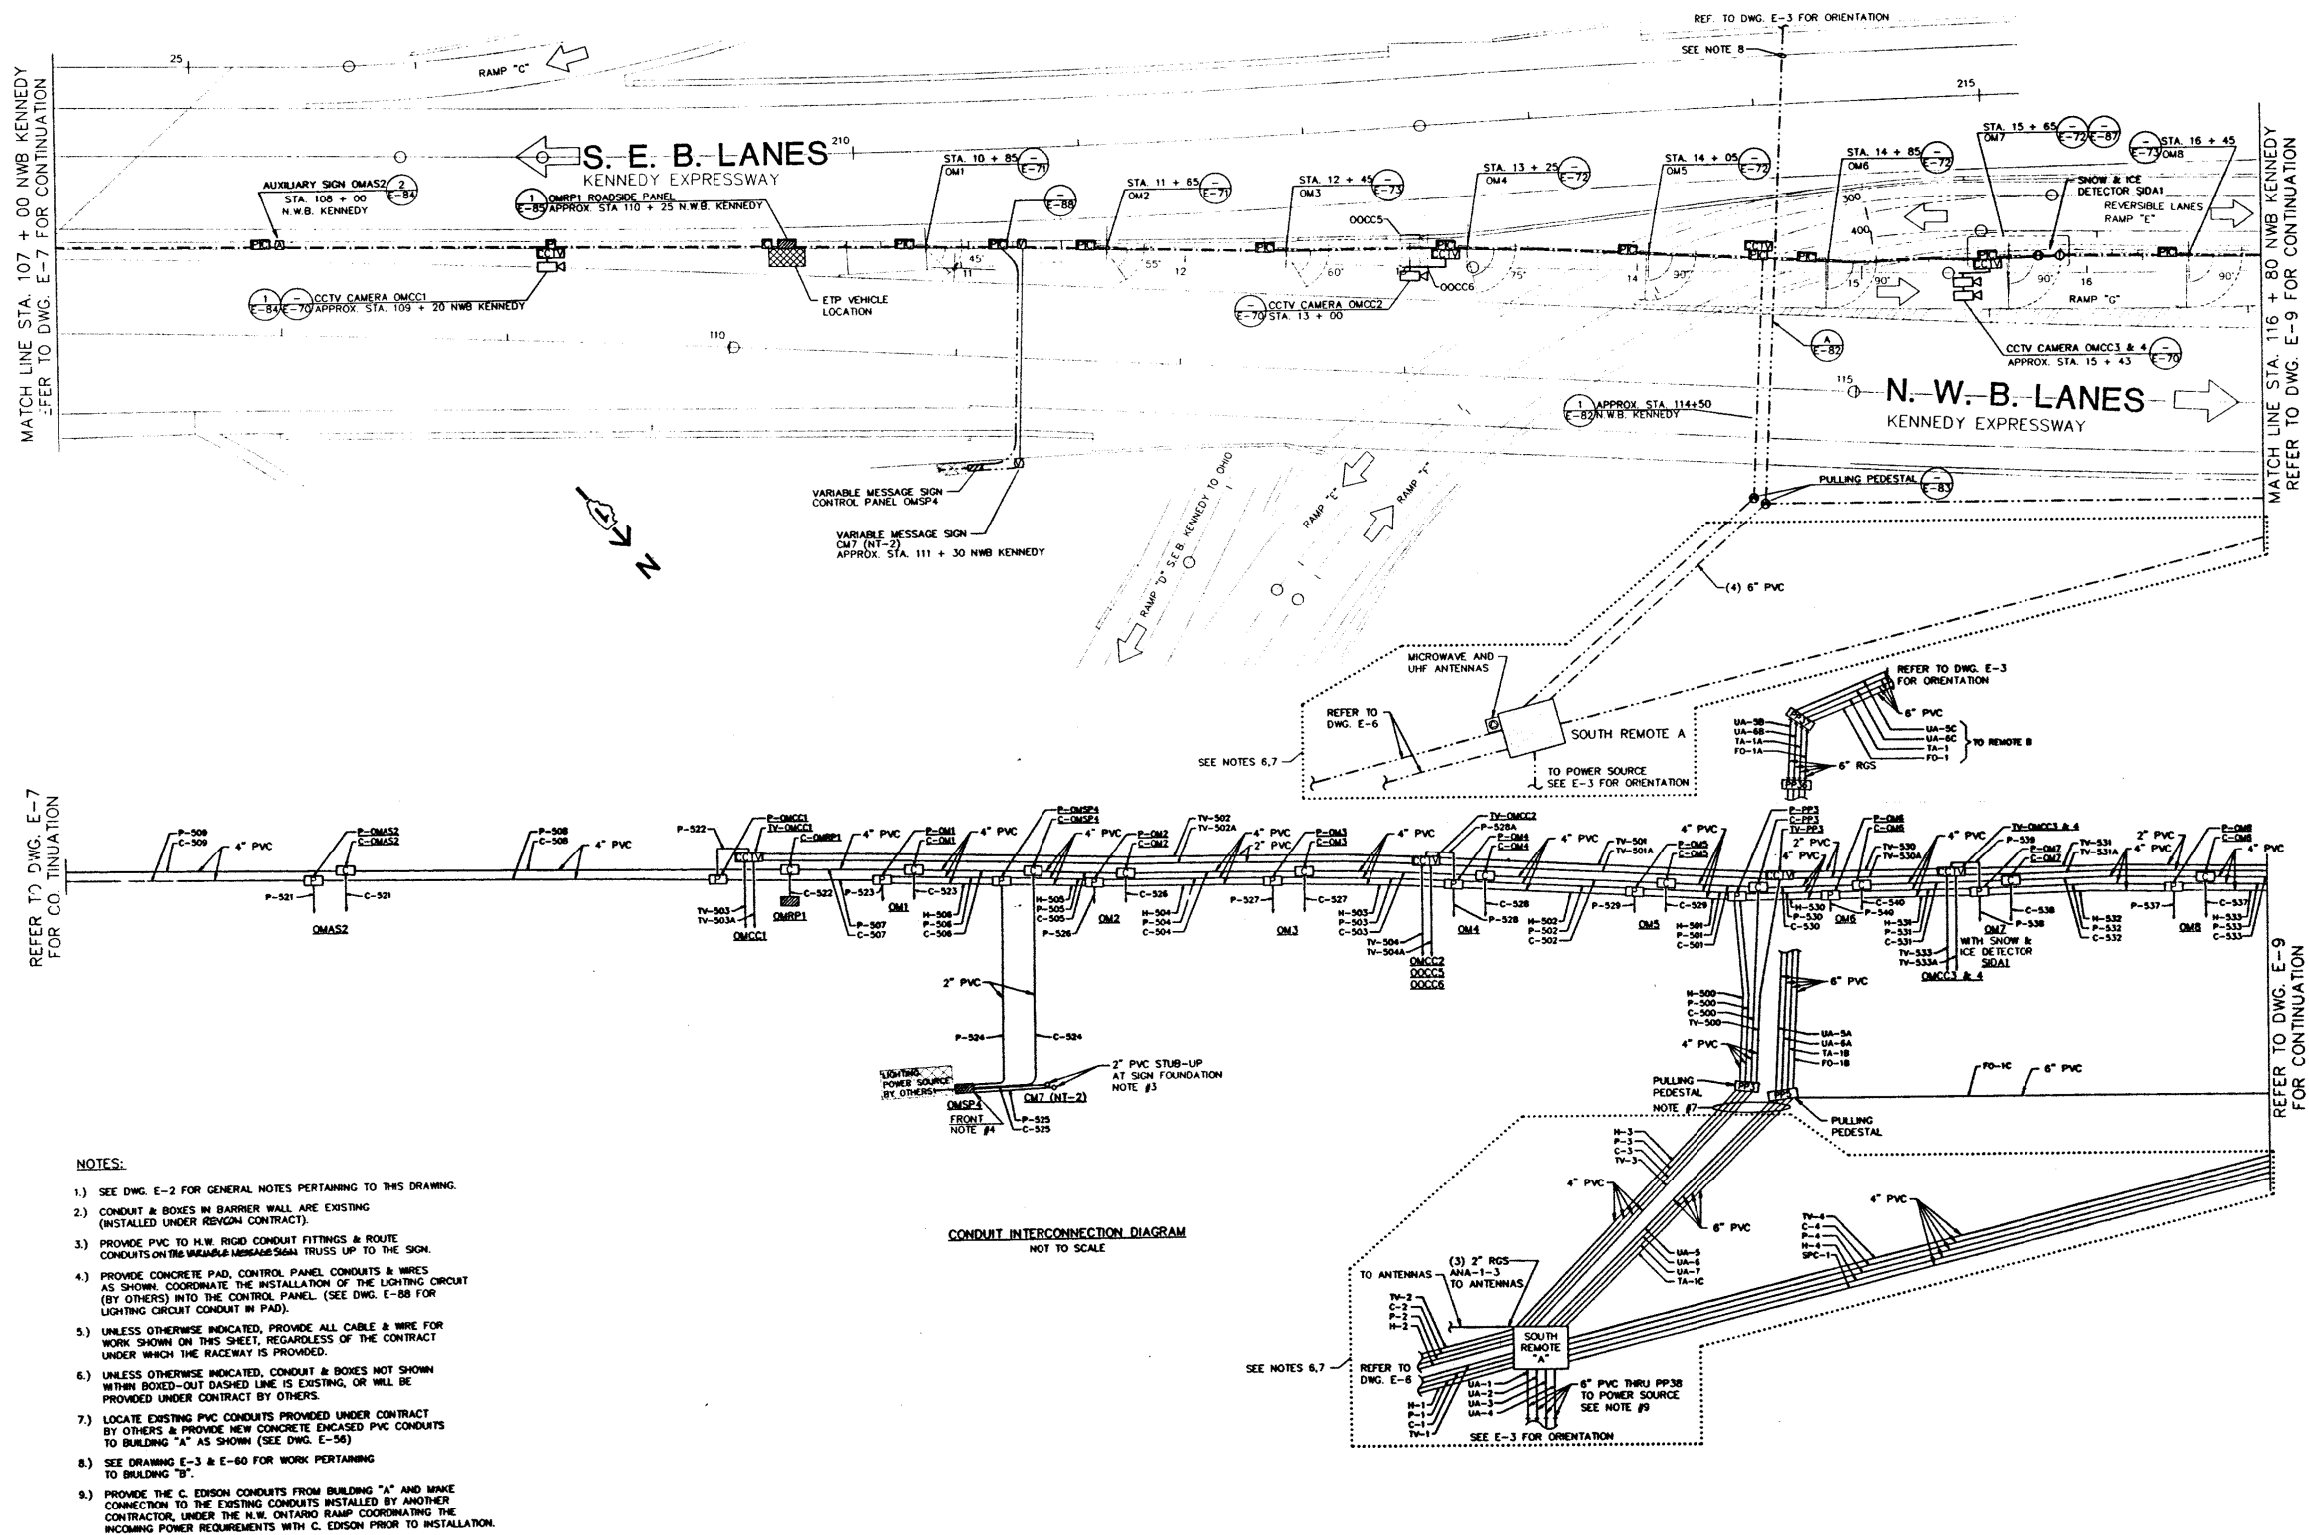

- NOTES:
- SEE DWG. E-2 FOR GENERAL NOTES PERTAINING TO THIS DRAWING.
  - CONDUIT & BOXES IN BARRIER WALL ARE EXISTING (INSTALLED UNDER REVISION CONTRACT).
  - PROVIDE PVC TO H.W. RIGID CONDUIT FITTINGS & ROUTE CONDUITS ON THE VARIABLE MESSAGE SIGN TRUSS UP TO THE SIGN.
  - PROVIDE CONCRETE PAD, CONTROL PANEL CONDUITS & WIRES AS SHOWN. COORDINATE THE INSTALLATION OF THE LIGHTING CIRCUIT (BY OTHERS) INTO THE CONTROL PANEL. (SEE DWG. E-58 FOR LIGHTING CIRCUIT CONDUIT IN PAD).
  - UNLESS OTHERWISE INDICATED, PROVIDE ALL CABLE & WIRE FOR WORK SHOWN ON THIS SHEET, REGARDLESS OF THE CONTRACT UNDER WHICH THE RACEWAY IS PROVIDED.
  - UNLESS OTHERWISE INDICATED, CONDUIT & BOXES NOT SHOWN WITHIN BOXED-OUT DASHED LINE IS EXISTING, OR WILL BE PROVIDED UNDER CONTRACT BY OTHERS.
  - LOCATE EXISTING PVC CONDUITS PROVIDED UNDER CONTRACT BY OTHERS & PROVIDE NEW CONCRETE ENCASED PVC CONDUITS TO BUILDING "A" AS SHOWN (SEE DWG. E-56).
  - SEE DRAWING E-3 & E-60 FOR WORK PERTAINING TO BUILDING "B".
  - PROVIDE THE C. EDISON CONDUITS FROM BUILDING "A" AND MAKE CONNECTION TO THE EXISTING CONDUITS INSTALLED BY ANOTHER CONTRACTOR, UNDER THE N.W. ONTARIO RAMP COORDINATING THE INCOMING POWER REQUIREMENTS WITH C. EDISON PRIOR TO INSTALLATION.

- NOTES:
- THE ABOVE DRAWINGS REPRESENT AS LET DESIGN TO AID CONTRACTOR IN ASCERTAINING EXISTING CONDITIONS.
  - CONTRACTOR SHALL CONTACT IDOT D1 TO REQUEST THE MOST UP TO DATE RECORD DRAWINGS AVAILABLE AT THE TIME OF LETTING.

FOR INFORMATION ONLY

J:\293\Task-2\CON\CADD\_Sheet\42.DWG\193-shd-details084.dgn

**SINGH**  
CONSULTING ENGINEERS  
www.singhinc.com

USER NAME = mgravida  
FILE NAME = 142.D160T93-shd-details084  
PLOT SCALE = 2.000000:1.000000  
PLOT DATE = 06-MAY-2015 15:52

DESIGNED - DJ/AG  
DRAWN - DS/AS  
CHECKED - 1Y  
DATE - 5/6/2015

REVISED -  
REVISED -  
REVISED -  
REVISED -



STATE OF ILLINOIS  
DEPARTMENT OF TRANSPORTATION

KENNEDY N.W.B. POWER & CONTROL PLAN

SCALE: NTS SHEET OF SHEETS STA. TO STA.

| F.A.I. RTE.               | SECTION   | COUNTY | TOTAL SHEETS | SHEET NO. |
|---------------------------|-----------|--------|--------------|-----------|
| 90/94                     | 2012-0521 | COOK   | 165          | 142       |
| CONTRACT NO. 60T93        |           |        |              |           |
| ILLINOIS FED. AID PROJECT |           |        |              |           |



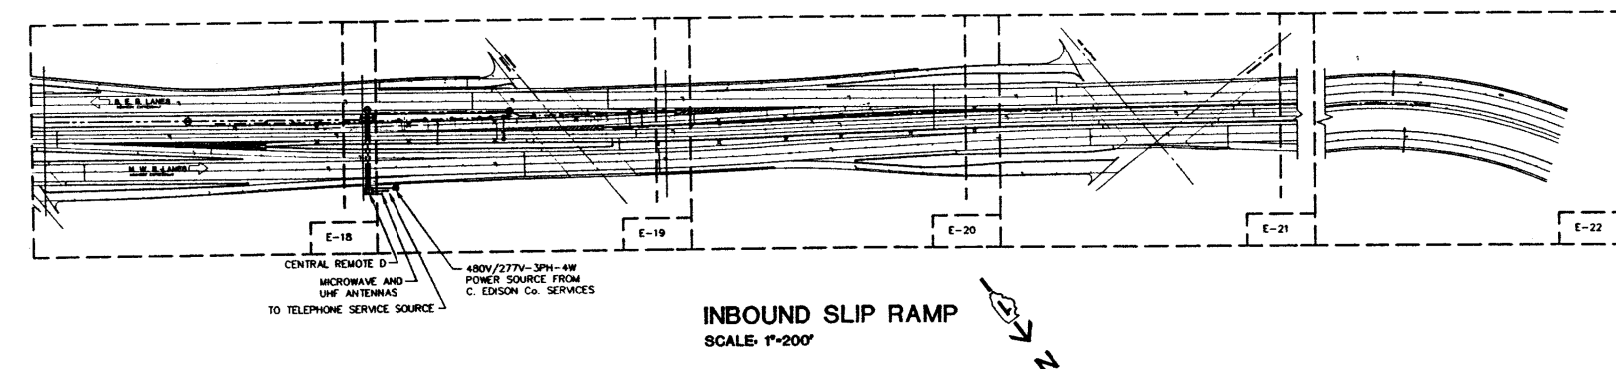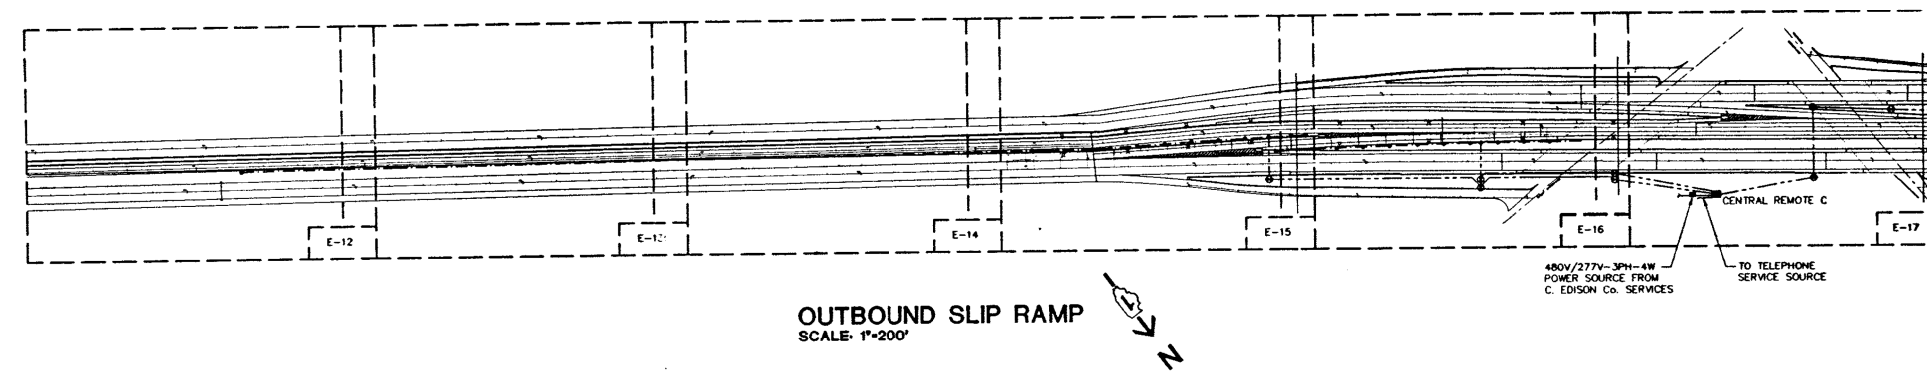


- NOTES:**
1. THE ABOVE DRAWINGS REPRESENT AS LET DESIGN TO AID CONTRACTOR IN ASCERTAINING EXISTING CONDITIONS.
  2. CONTRACTOR SHALL CONTACT IDOT D1 TO REQUEST THE MOST UP TO DATE RECORD DRAWINGS AVAILABLE AT THE TIME OF LETTING.

**FOR INFORMATION ONLY**

J:\293\Task-2\CON\CADD\_Sheet\43.D160T93-sh1-details085.dgn

|                                                          |                                        |  |                  |           |                                                   |                                                 |       |    |        |                    |           |                           |              |           |
|----------------------------------------------------------|----------------------------------------|--|------------------|-----------|---------------------------------------------------|-------------------------------------------------|-------|----|--------|--------------------|-----------|---------------------------|--------------|-----------|
| <b>SINGH</b><br>CONSULTING ENGINEERS<br>www.singhinc.com | USER NAME = mgarvido                   |  | DESIGNED - DJ/AG | REVISED - | STATE OF ILLINOIS<br>DEPARTMENT OF TRANSPORTATION | INBOUND AND OUTBOUND SLIP RAMP ORIENTATION PLAN |       |    |        | F.A.I. RTE.        | SECTION   | COUNTY                    | TOTAL SHEETS | SHEET NO. |
|                                                          | FILE NAME = 143.D160T93-sh1-details085 |  | DRAWN - DS/AS    | REVISED - |                                                   |                                                 |       |    |        | 90/94              | 2012-0521 | COOK                      | 165          | 143       |
|                                                          | PLOT SCALE = 2.000000:1.000000         |  | CHECKED - 1Y     | REVISED - |                                                   |                                                 |       |    |        | CONTRACT NO. 60T93 |           |                           |              |           |
|                                                          | PLOT DATE = 06-MAY-2015 15:53          |  | DATE - 5/6/2015  | REVISED - |                                                   | SCALE: NTS                                      | SHEET | OF | SHEETS | STA.               | TO STA.   | ILLINOIS FED. AID PROJECT |              |           |

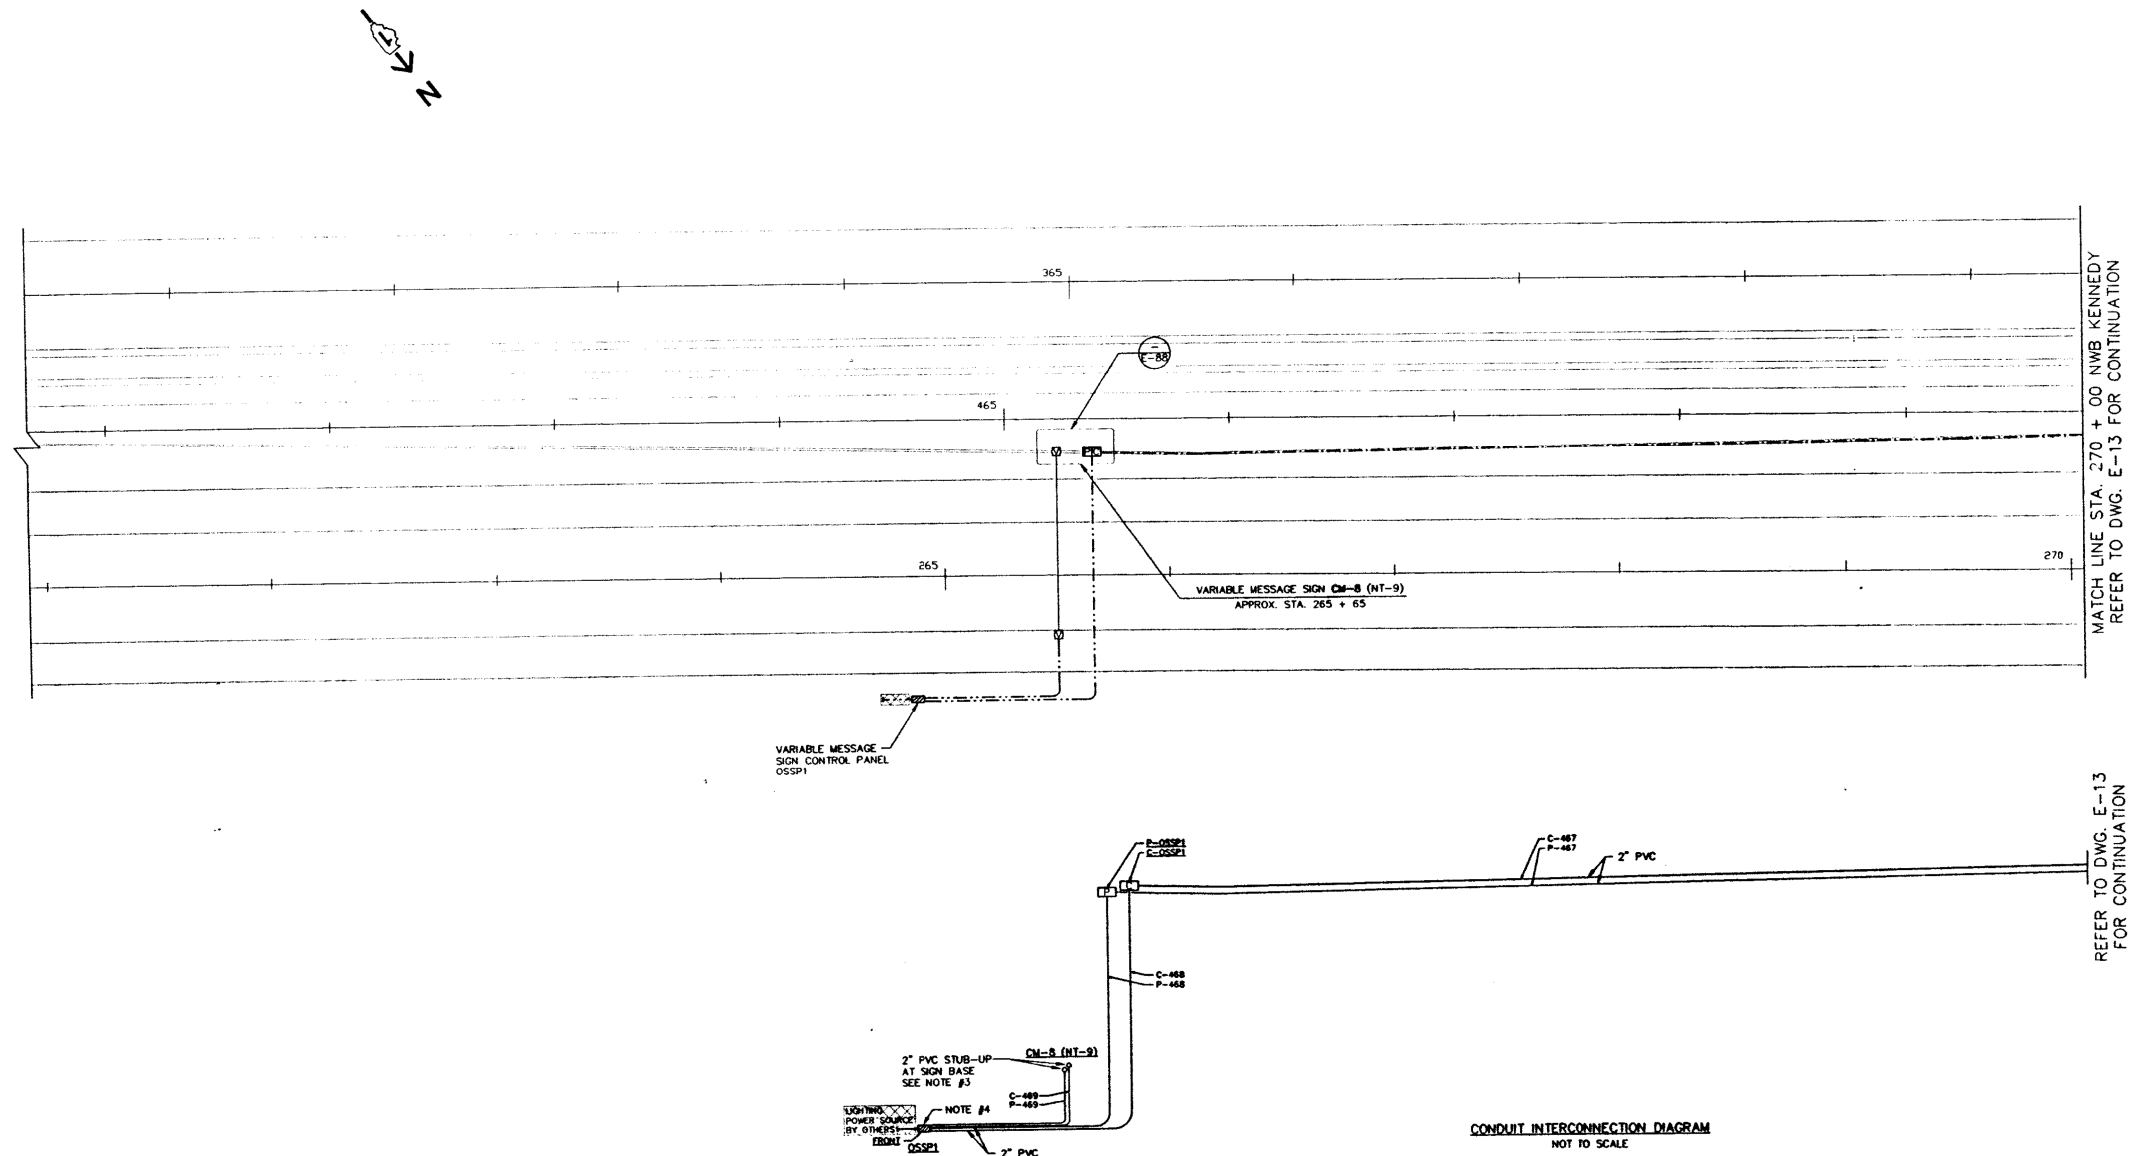

- NOTES:
- 1.) SEE DWG. E-2 FOR GENERAL NOTES PERTAINING TO THIS DRAWING.
  - 2.) CONDUIT & BOXES IN BARRIER WALL ARE EXISTING (INSTALLED UNDER REVENUE CONTRACT).
  - 3.) PROVIDE PVC TO H.W. RIGID CONDUIT FITTINGS & ROUTE CONDUITS ON THE VARIABLE MESSAGE SIGN TRUSS UP TO THE SIGN.
  - 4.) PROVIDE CONCRETE PAD, CONTROL PANEL AS SHOWN. COORDINATE THE INSTALLATION OF THE LIGHTING CIRCUIT (BY OTHERS) INTO THE CONTROL PANEL. (SEE DWG. E-08 FOR LIGHTING CIRCUIT CONDUIT IN PAD).
  - 5.) UNLESS OTHERWISE INDICATED, PROVIDE ALL CABLE & WIRE FOR WORK SHOWN ON THIS SHEET, REGARDLESS OF THE CONTRACT UNDER WHICH THE RAMPWAY IS PROVIDED.

- NOTES:
1. THE ABOVE DRAWINGS REPRESENT AS LET DESIGN TO AID CONTRACTOR IN ASCERTAINING EXISTING CONDITIONS.
  2. CONTRACTOR SHALL CONTACT IDOT D1 TO REQUEST THE MOST UP TO DATE RECORD DRAWINGS AVAILABLE AT THE TIME OF LETTING.

FOR INFORMATION ONLY

J:\293\Task-2\CON\CADD\_Sheet\44.D160T93-sh1-details086.dgn

**SINGH**  
CONSULTING ENGINEERS  
www.singhinc.com


|                                        |                  |           |
|----------------------------------------|------------------|-----------|
| USER NAME = mgarvido                   | DESIGNED - DJ/AG | REVISED - |
| FILE NAME = 144.D160T93-sh1-details086 | DRAWN - DS/AS    | REVISED - |
| PLOT SCALE = 2.000000:1.000000         | CHECKED - 1Y     | REVISED - |
| PLOT DATE = 06-MAY-2015 15:54          | DATE - 5/6/2015  | REVISED - |

STATE OF ILLINOIS  
DEPARTMENT OF TRANSPORTATION

| OUTBOUND SLIP RAMP POWER & CONTROL PLAN |       |           |              |
|-----------------------------------------|-------|-----------|--------------|
| SCALE: NTS                              | SHEET | OF SHEETS | STA. TO STA. |

| F.A.I. RTE.               | SECTION   | COUNTY | TOTAL SHEETS | SHEET NO. |
|---------------------------|-----------|--------|--------------|-----------|
| 90/94                     | 2012-0521 | COOK   | 165          | 144       |
| CONTRACT NO. 60T93        |           |        |              |           |
| ILLINOIS FED. AID PROJECT |           |        |              |           |

J:\293\Task-2\CON\CADD\_Sheet\45.D160T93-sh1-details087.dgn

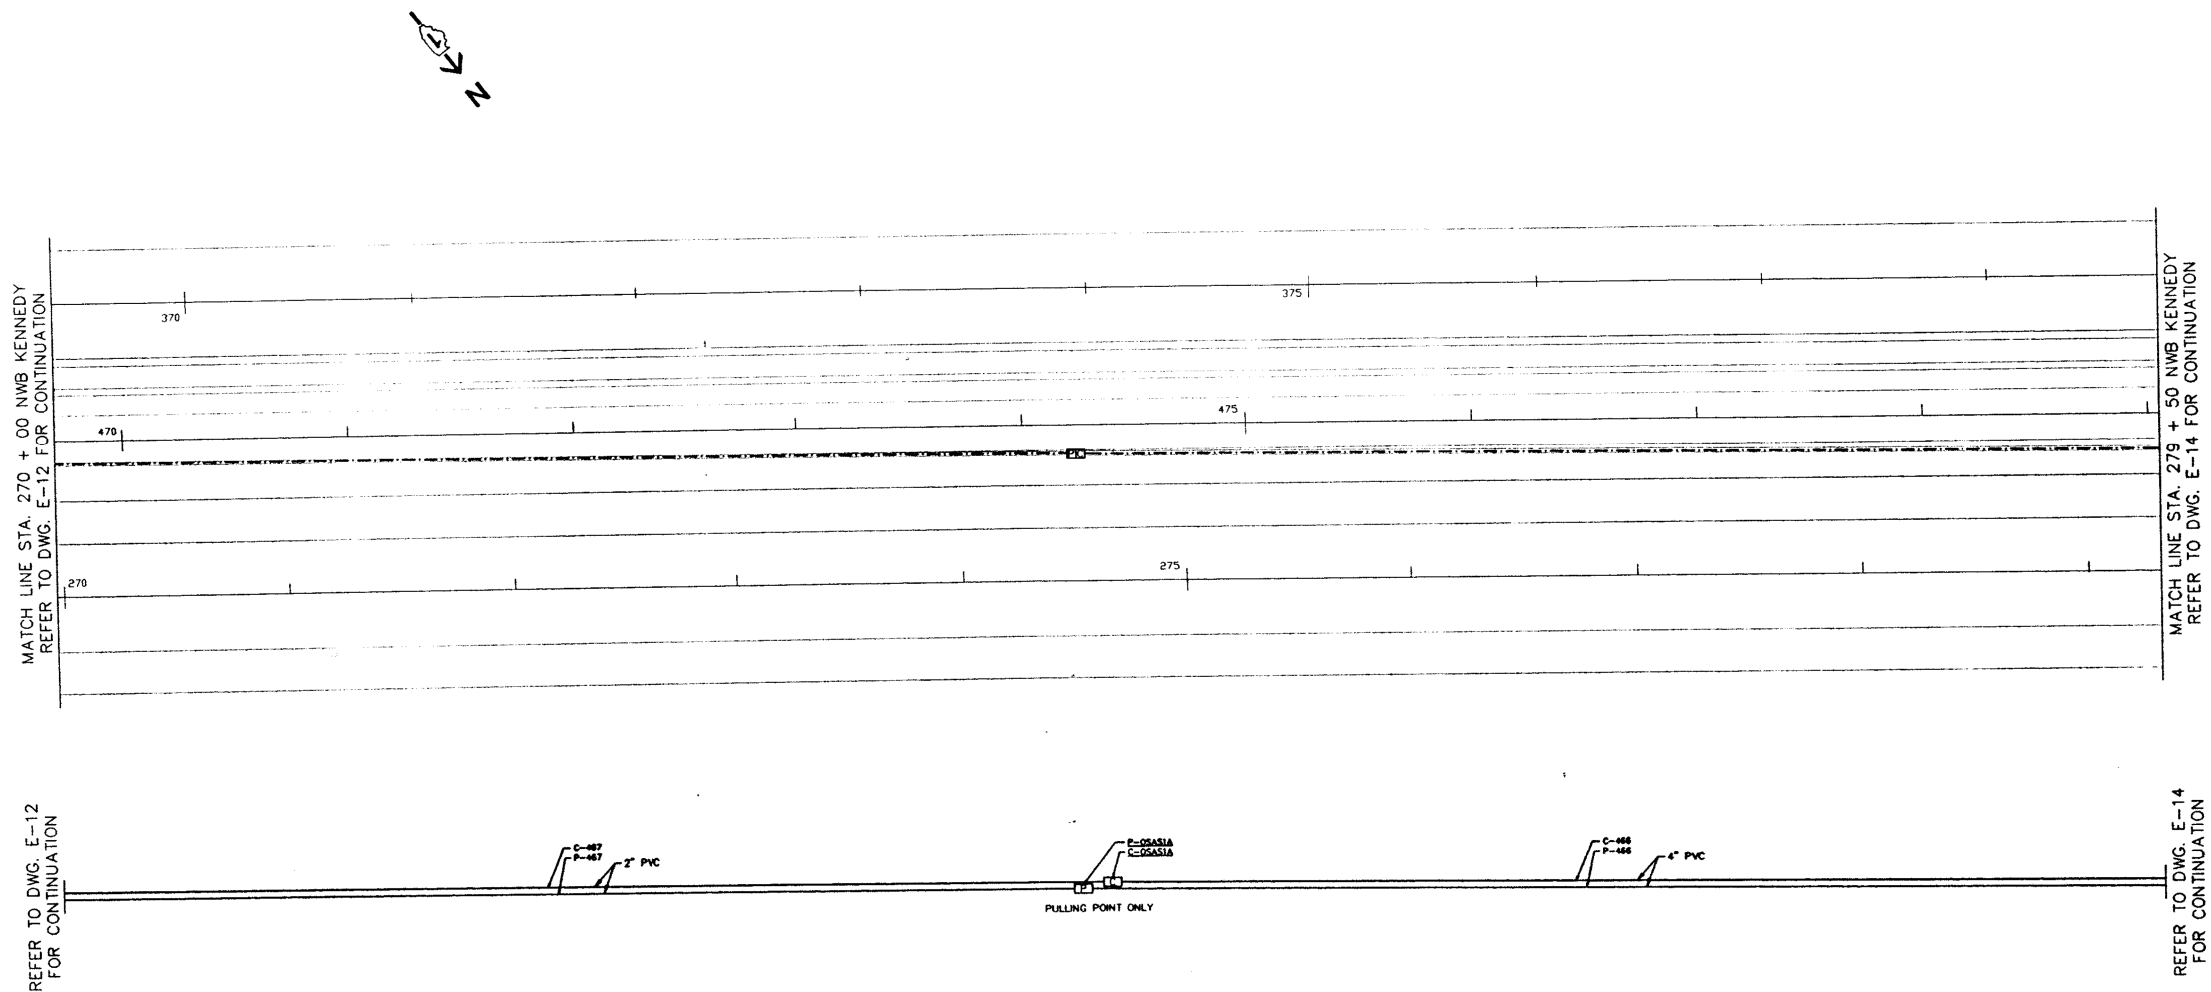

CONDUIT INTERCONNECTION DIAGRAM  
NOT TO SCALE

NOTES:

- 1.) SEE DWG. E-2 FOR GENERAL NOTES PERTAINING TO THIS DRAWING.
- 2.) CONDUIT & BOXES IN BARRIER WALL ARE EXISTING (INSTALLED UNDER PREVIOUS CONTRACT).
- 3.) UNLESS OTHERWISE INDICATED, PROVIDE ALL CABLE & WIRE FOR WORK SHOWN ON THIS SHEET, REGARDLESS OF THE CONTRACT UNDER WHICH THE RACEWAY IS PROVIDED.

NOTES:

1. THE ABOVE DRAWINGS REPRESENT AS LET DESIGN TO AID CONTRACTOR IN ASCERTAINING EXISTING CONDITIONS.
2. CONTRACTOR SHALL CONTACT IDOT D1 TO REQUEST THE MOST UP TO DATE RECORD DRAWINGS AVAILABLE AT THE TIME OF LETTING.

FOR INFORMATION ONLY

**SINGH**  
CONSULTING ENGINEERS  
www.singhinc.com

USER NAME = mgarvida  
FILE NAME = 145.D160T93-sh1-details087  
PLOT SCALE = 2.000000:1.000000  
PLOT DATE = 06-MAY-2015 15:55

DESIGNED - DJ/AG  
DRAWN - DS/AS  
CHECKED - 1Y  
DATE - 5/6/2015

REVISED -  
REVISED -  
REVISED -  
REVISED -


STATE OF ILLINOIS  
DEPARTMENT OF TRANSPORTATION

OUTBOUND SLIP RAMP POWER & CONTROL PLAN

SCALE: NTS SHEET OF SHEETS STA. TO STA.

|                           |           |        |                 |              |
|---------------------------|-----------|--------|-----------------|--------------|
| F.A.I.<br>RTE.            | SECTION   | COUNTY | TOTAL<br>SHEETS | SHEET<br>NO. |
| 90/94                     | 2012-0521 | COOK   | 165             | 145          |
| CONTRACT NO. 60T93        |           |        |                 |              |
| ILLINOIS FED. AID PROJECT |           |        |                 |              |

J:\293\Task-2\CON\CADD\_Sheet\46.D160T93-sh1-details088.dgn

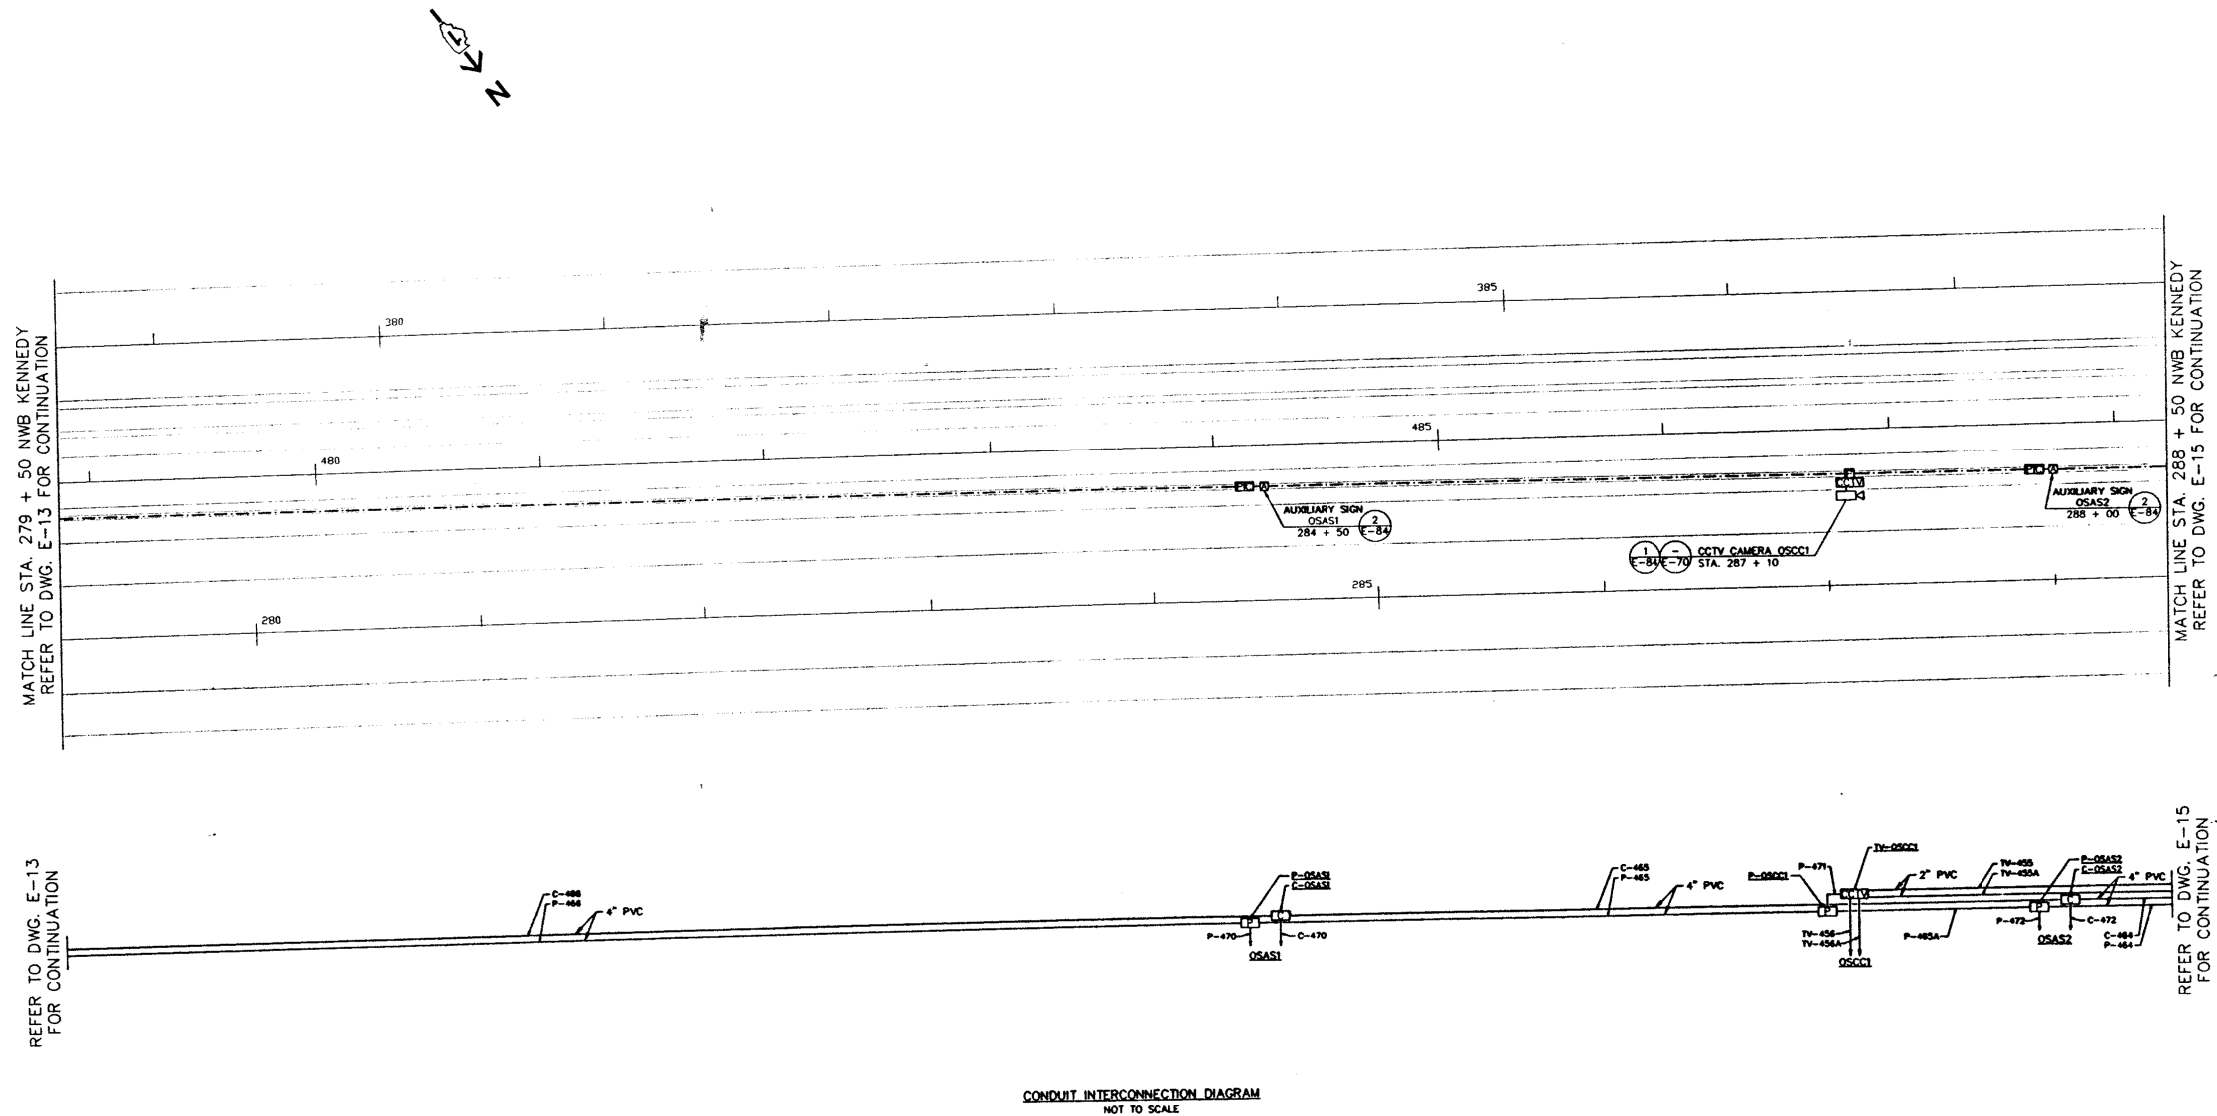

NOTES:

- 1.) SEE DWG. E-2 FOR GENERAL NOTES PERTAINING TO THIS DRAWING.
- 2.) CONDUIT & BOXES IN BARRIER WALL ARE EXISTING (INSTALLED UNDER REVENGE CONTRACT).
- 3.) UNLESS OTHERWISE INDICATED, PROVIDE ALL CABLE & WIRE FOR WORK SHOWN ON THIS SHEET, REGARDLESS OF THE CONTRACT UNDER WHICH THE RAMPWAY IS PROVIDED.

NOTES:

1. THE ABOVE DRAWINGS REPRESENT AS LET DESIGN TO AID CONTRACTOR IN ASCERTAINING EXISTING CONDITIONS.
2. CONTRACTOR SHALL CONTACT IDOT D1 TO REQUEST THE MOST UP TO DATE RECORD DRAWINGS AVAILABLE AT THE TIME OF LETTING.

FOR INFORMATION ONLY

**SINGH**  
CONSULTING ENGINEERS  
www.singhinc.com


|                                        |                  |           |
|----------------------------------------|------------------|-----------|
| USER NAME = mgarvido                   | DESIGNED - DJ/AG | REVISED - |
| FILE NAME = 146.D160T93-sh1-details088 | DRAWN - DS/AS    | REVISED - |
| PLOT SCALE = 2.000000:1.000000         | CHECKED - 1Y     | REVISED - |
| PLOT DATE = 06-MAY-2015 15:56          | DATE - 5/6/2015  | REVISED - |

STATE OF ILLINOIS  
DEPARTMENT OF TRANSPORTATION

OUTBOUND SLIP RAMP POWER & CONTROL PLAN

SCALE: NTS SHEET OF SHEETS STA. TO STA.

| F.A.I. RTE.               | SECTION   | COUNTY | TOTAL SHEETS | SHEET NO. |
|---------------------------|-----------|--------|--------------|-----------|
| 90/94                     | 2012-0521 | COOK   | 165          | 146       |
| CONTRACT NO. 60T93        |           |        |              |           |
| ILLINOIS FED. AID PROJECT |           |        |              |           |

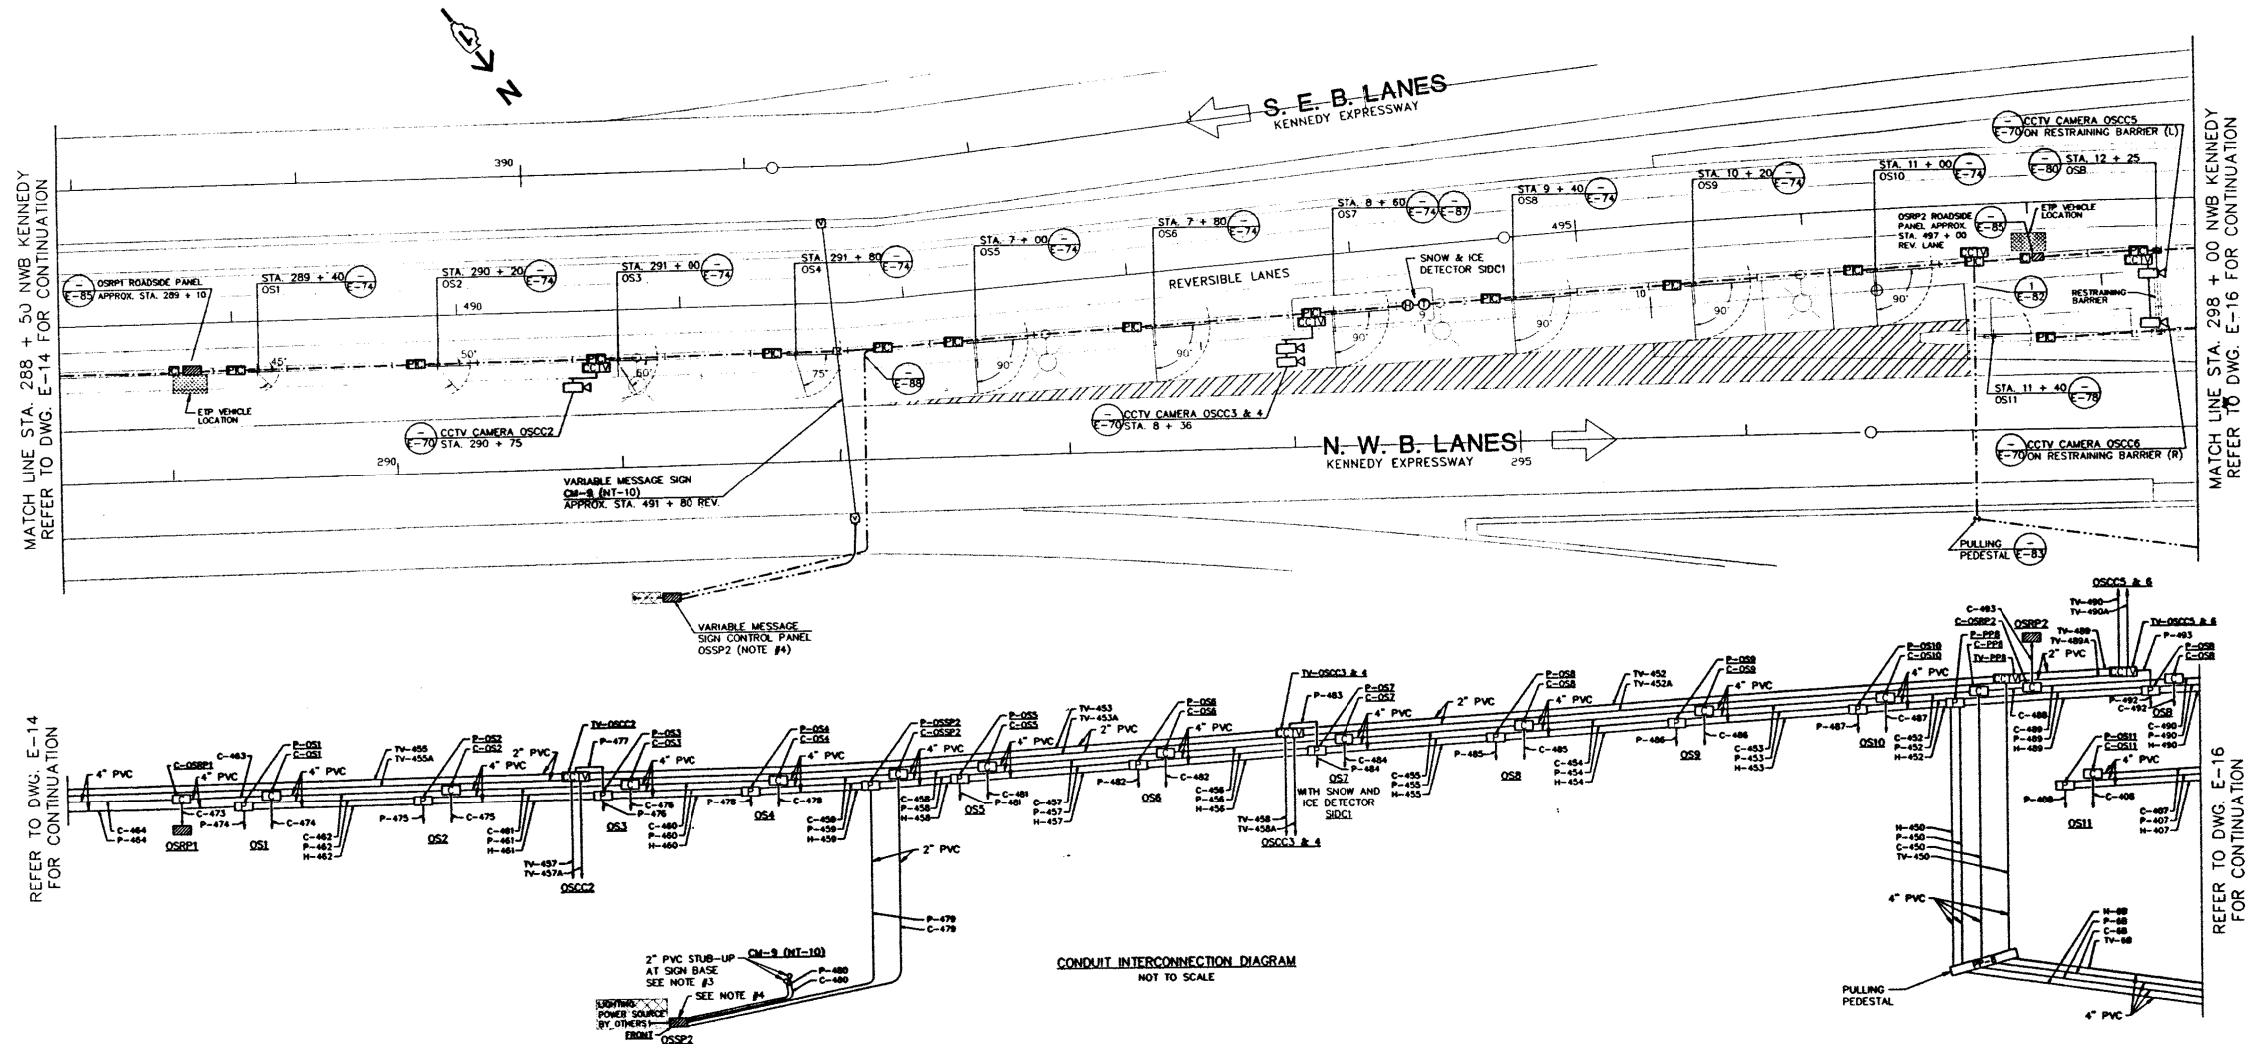

#### NOTES:

- SEE DWG. E-2 FOR GENERAL NOTES PERTAINING TO THIS DRAWING.
- CONDUIT & BOXES IN BARRIER WALL ARE EXISTING (INSTALLED UNDER REVENUE CONTRACT).
- PROVIDE PVC TO H.W. RIGID CONDUIT FITTINGS & ROUTE CONDUITS OUTLINE VARIABLE MESSAGE SIGN/STREET LIGHTS UP TO THE SIGN.
- PROVIDE CONCRETE PAD, CONTROL PANEL, CONDUITS & WIRES AS SHOWN. COORDINATE THE INSTALLATION OF THE LIGHTING CIRCUIT (BY OTHERS) INTO THE CONTROL PANEL. (SEE DWG. E-88 FOR LIGHTING CIRCUIT CONDUIT IN PAD).
- UNLESS OTHERWISE INDICATED, PROVIDE ALL CABLE & WIRE FOR WORK SHOWN ON THIS SHEET, REGARDLESS OF THE CONTRACT UNDER WHICH THE RACEWAY IS PROVIDED.
- UNLESS OTHERWISE INDICATED, CONDUIT & BOXES NOT SHOWN WITHIN BOXED-OUT DASHED LINE IS EXISTING, OR WILL BE PROVIDED UNDER CONTRACT BY OTHERS.

#### NOTES:

- THE ABOVE DRAWINGS REPRESENT AS LET DESIGN TO AID CONTRACTOR IN ASCERTAINING EXISTING CONDITIONS.
- CONTRACTOR SHALL CONTACT IDOT D1 TO REQUEST THE MOST UP TO DATE RECORD DRAWINGS AVAILABLE AT THE TIME OF LETTING.

**FOR INFORMATION ONLY**

**SINGH**  
CONSULTING ENGINEERS  
www.singhinc.com

USER NAME = mgravida  
FILE NAME = 147\_D160T93-shd-details089  
PLOT SCALE = 2.000000:1.000000  
PLOT DATE = 06-MAY-2015 15:56

DESIGNED - DJ/AG  
DRAWN - DS/AS  
CHECKED - 1Y  
DATE - 5/6/2015



REVISED -  
REVISED -  
REVISED -  
REVISED -

STATE OF ILLINOIS  
DEPARTMENT OF TRANSPORTATION

OUTBOUND SLIP RAMP POWER & CONTROL PLAN

SCALE: NTS SHEET OF SHEETS STA. TO STA.

|                           |           |        |              |           |
|---------------------------|-----------|--------|--------------|-----------|
| F.A.I. RTE.               | SECTION   | COUNTY | TOTAL SHEETS | SHEET NO. |
| 90/94                     | 2012-0521 | COOK   | 165          | 147       |
| CONTRACT NO. 60T93        |           |        |              |           |
| ILLINOIS FED. AID PROJECT |           |        |              |           |

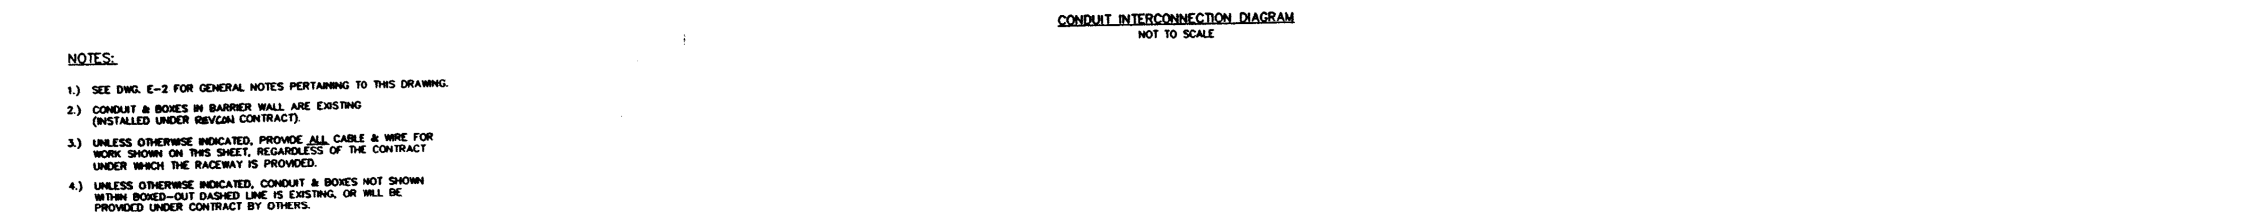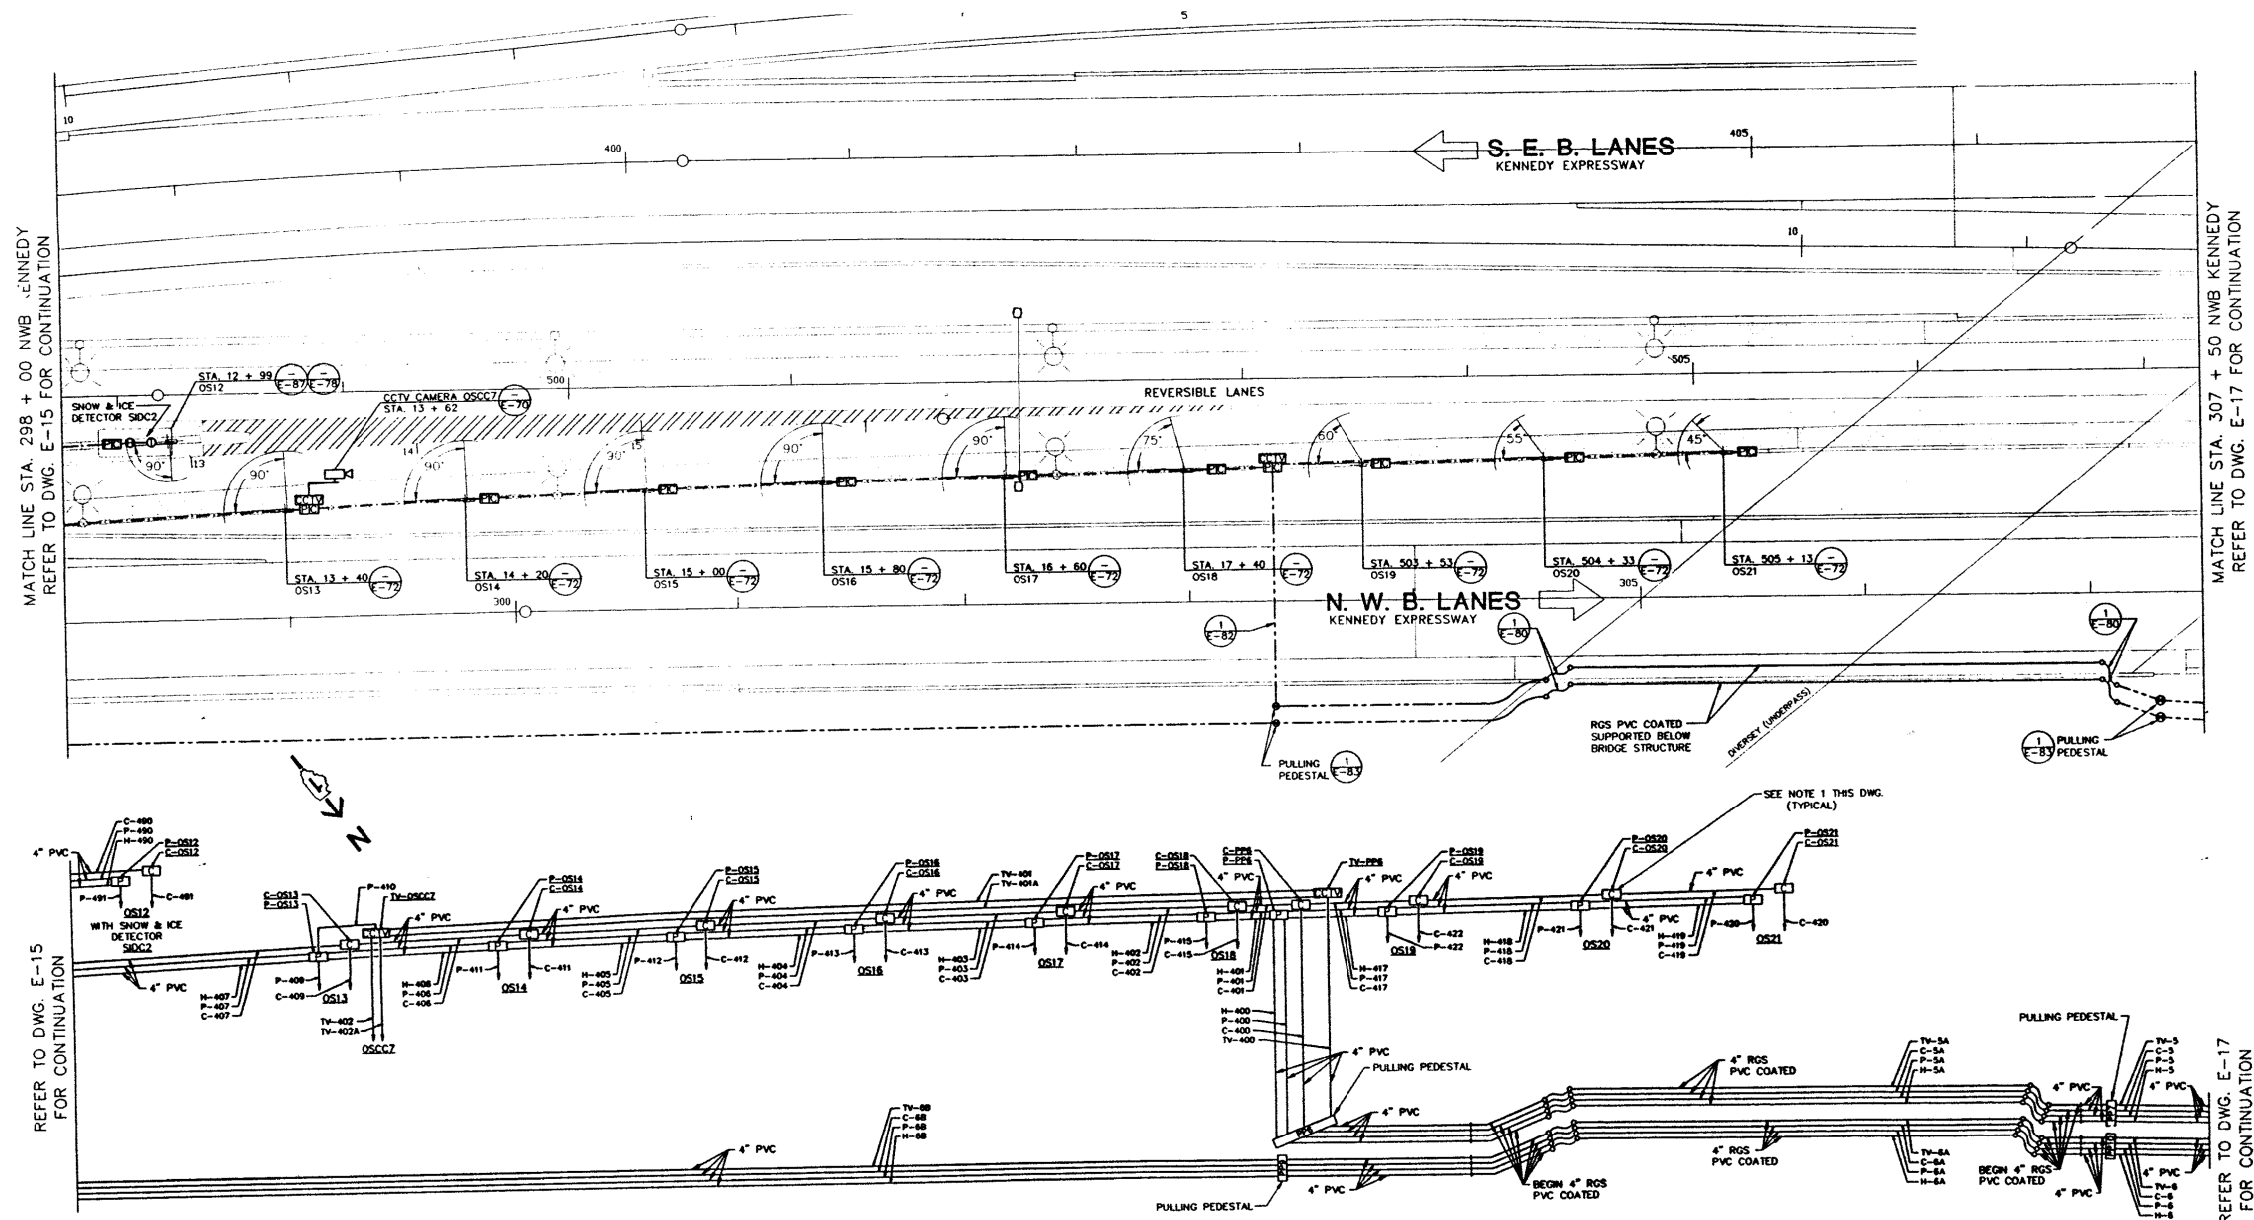

- NOTES:**
1. SEE DWG. E-2 FOR GENERAL NOTES PERTAINING TO THIS DRAWING.
  2. CONDUIT & BOXES IN BARRIER WALL ARE EXISTING (INSTALLED UNDER REVCON CONTRACT).
  3. UNLESS OTHERWISE INDICATED, PROVIDE ALL CABLE & WIRE FOR WORK SHOWN ON THIS SHEET, REGARDLESS OF THE CONTRACT UNDER WHICH THE RACEWAY IS PROVIDED.
  4. UNLESS OTHERWISE INDICATED, CONDUIT & BOXES NOT SHOWN WITHIN BOXED-OUT DASHED LINE IS EXISTING, OR WILL BE PROVIDED UNDER CONTRACT BY OTHERS.

- NOTES:**
1. THE ABOVE DRAWINGS REPRESENT AS LET DESIGN TO AID CONTRACTOR IN ASCERTAINING EXISTING CONDITIONS.
  2. CONTRACTOR SHALL CONTACT IDOT D1 TO REQUEST THE MOST UP TO DATE RECORD DRAWINGS AVAILABLE AT THE TIME OF LETTING.

**FOR INFORMATION ONLY**

J:\293\Task-2\CON\CADD\_Sheet\48.Dwg\193-sh1-details090.dwg

**SINGH**  
CONSULTING ENGINEERS  
www.singhinc.com


|                                        |                  |           |
|----------------------------------------|------------------|-----------|
| USER NAME = mgarvada                   | DESIGNED - DJ/AG | REVISED - |
| FILE NAME = 148_D160T93-sh1-details090 | DRAWN - DS/AS    | REVISED - |
| PLOT SCALE = 2.000000:1.000000         | CHECKED - 1Y     | REVISED - |
| PLOT DATE = 06-MAY-2015 15:57          | DATE - 5/6/2015  | REVISED - |

STATE OF ILLINOIS  
DEPARTMENT OF TRANSPORTATION

| OUTBOUND SLIP RAMP POWER & CONTROL PLAN |       |           |              |
|-----------------------------------------|-------|-----------|--------------|
| SCALE: NTS                              | SHEET | OF SHEETS | STA. TO STA. |

| F.A.I. RTE.               | SECTION   | COUNTY | TOTAL SHEETS | SHEET NO. |
|---------------------------|-----------|--------|--------------|-----------|
| 90/94                     | 2012-0521 | COOK   | 165          | 148       |
| CONTRACT NO. 60T93        |           |        |              |           |
| ILLINOIS FED. AID PROJECT |           |        |              |           |



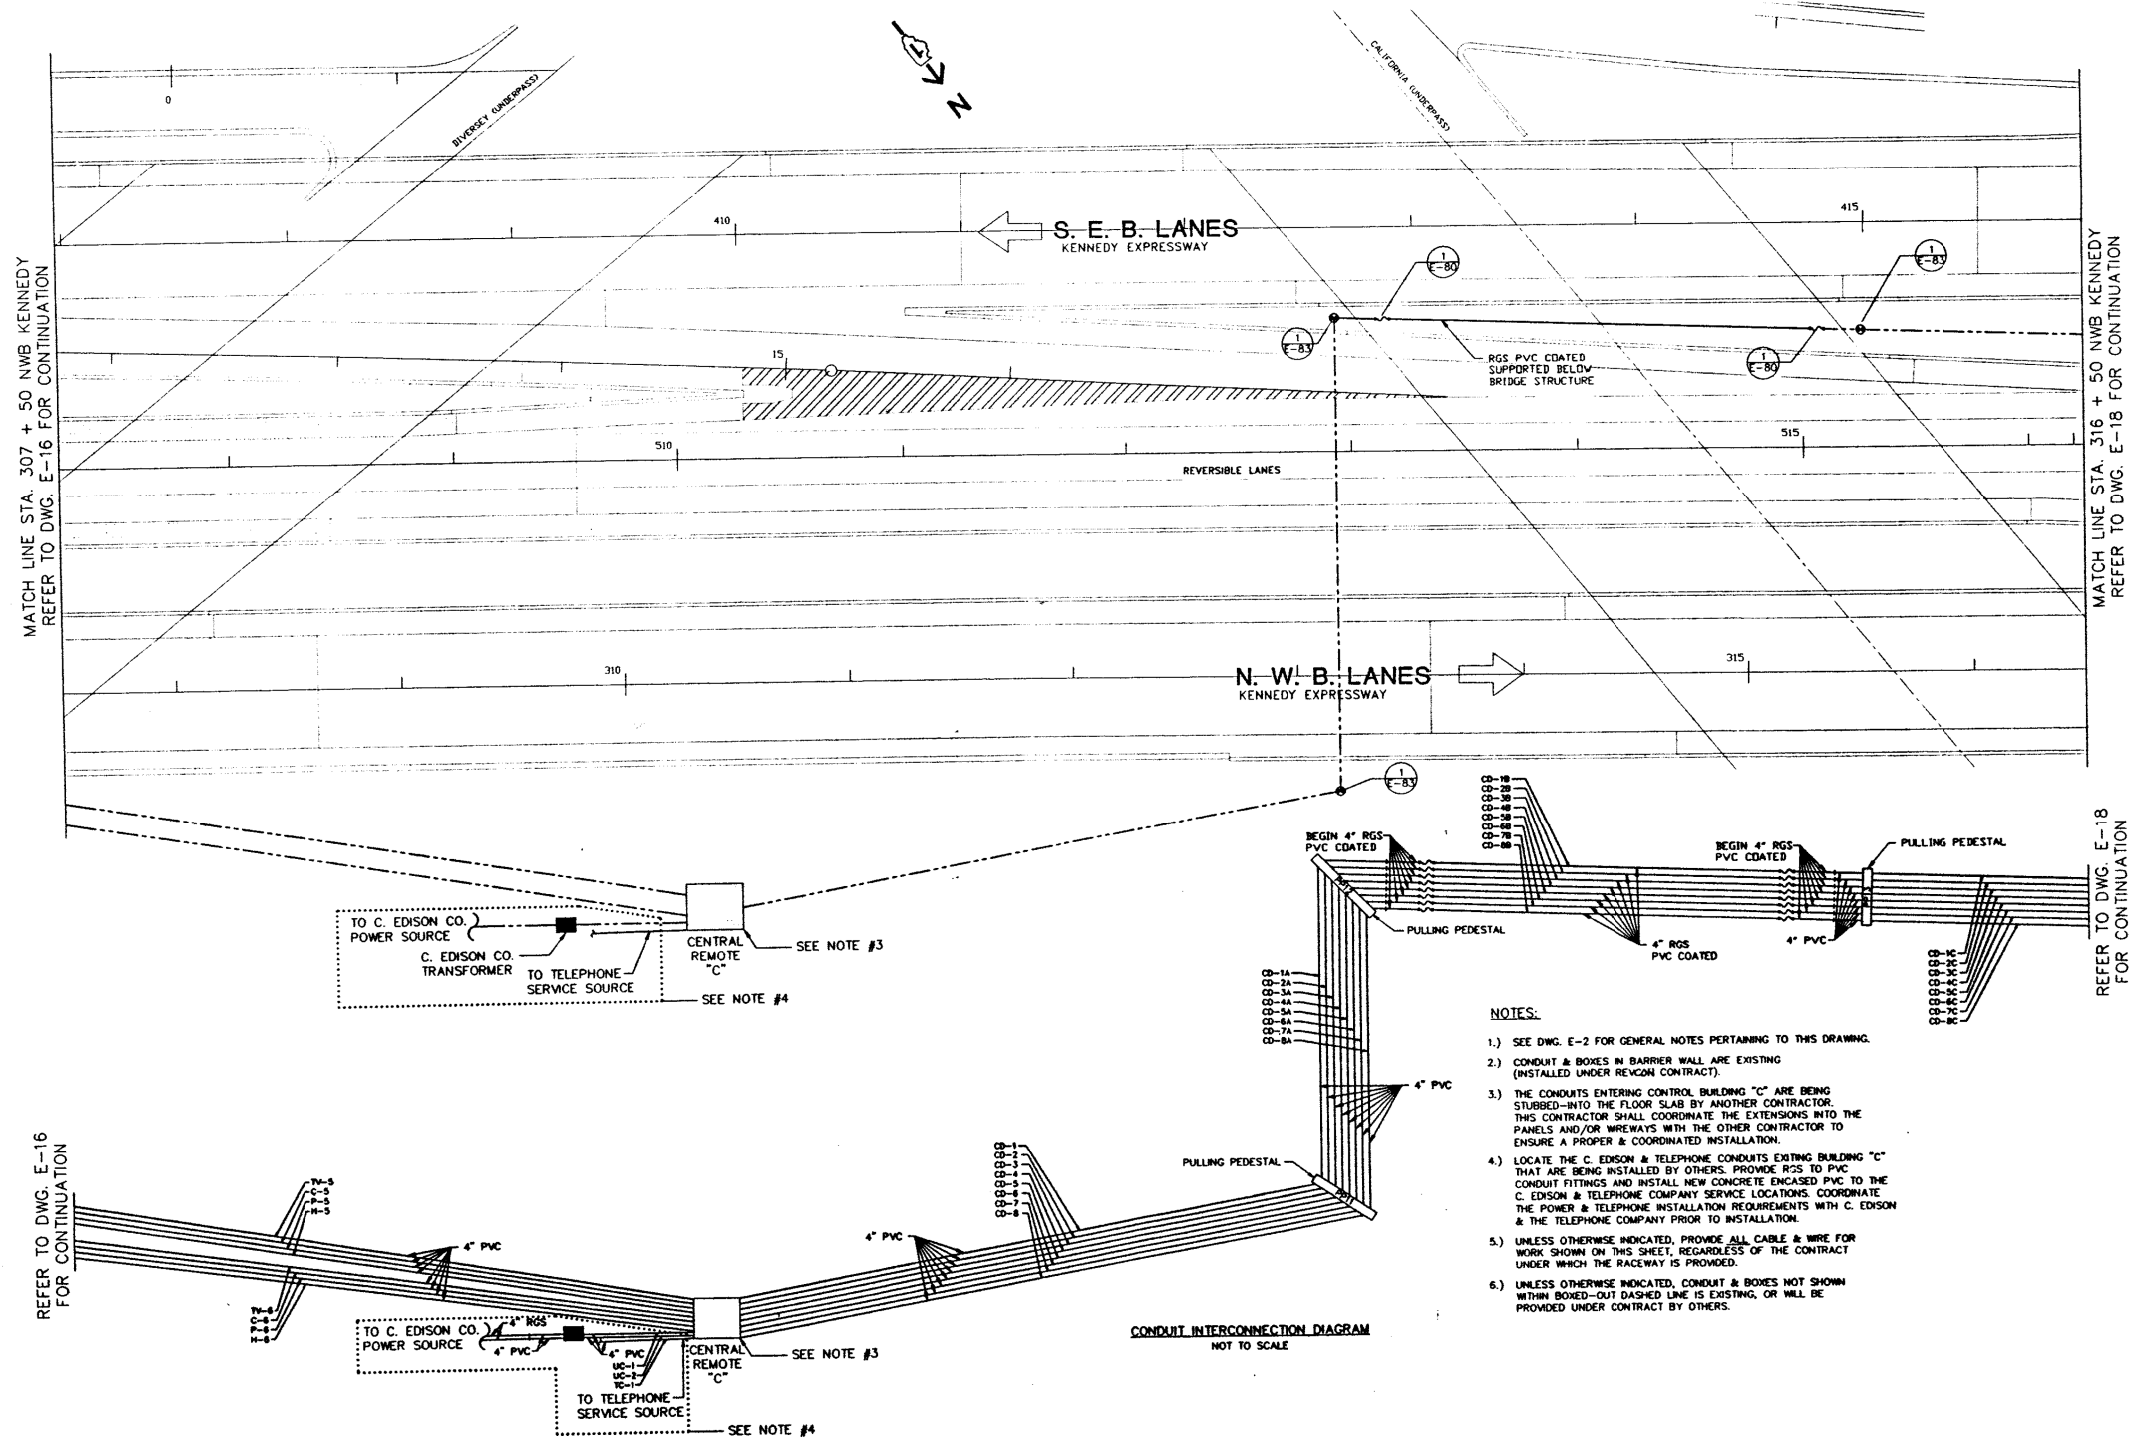

# NOTES:

- THE ABOVE DRAWINGS REPRESENT AS LET DESIGN TO AID CONTRACTOR IN ASCERTAINING EXISTING CONDITIONS.
- CONTRACTOR SHALL CONTACT IDOT D1 TO REQUEST THE MOST UP TO DATE RECORD DRAWINGS AVAILABLE AT THE TIME OF LETTING.

**FOR INFORMATION ONLY**

**SINGH**  
CONSULTING ENGINEERS  
www.singhinc.com


|                                        |                  |           |
|----------------------------------------|------------------|-----------|
| USER NAME = mgarvada                   | DESIGNED - DJ/AG | REVISED - |
| FILE NAME = 149_D160T93-sh1-details091 | DRAWN - DS/AS    | REVISED - |
| PLOT SCALE = 2.000000:1.000000         | CHECKED - 1Y     | REVISED - |
| PLOT DATE = 06-MAY-2015 15:59          | DATE - 5/6/2015  | REVISED - |

STATE OF ILLINOIS  
DEPARTMENT OF TRANSPORTATION

OUTBOUND SLIP RAMP POWER & CONTROL PLAN

SCALE: NTS SHEET OF SHEETS STA. TO STA.

| F.A.I. RTE.               | SECTION   | COUNTY | TOTAL SHEETS | SHEET NO. |
|---------------------------|-----------|--------|--------------|-----------|
| 90/94                     | 2012-0521 | COOK   | 165          | 149       |
| CONTRACT NO. 60T93        |           |        |              |           |
| ILLINOIS FED. AID PROJECT |           |        |              |           |

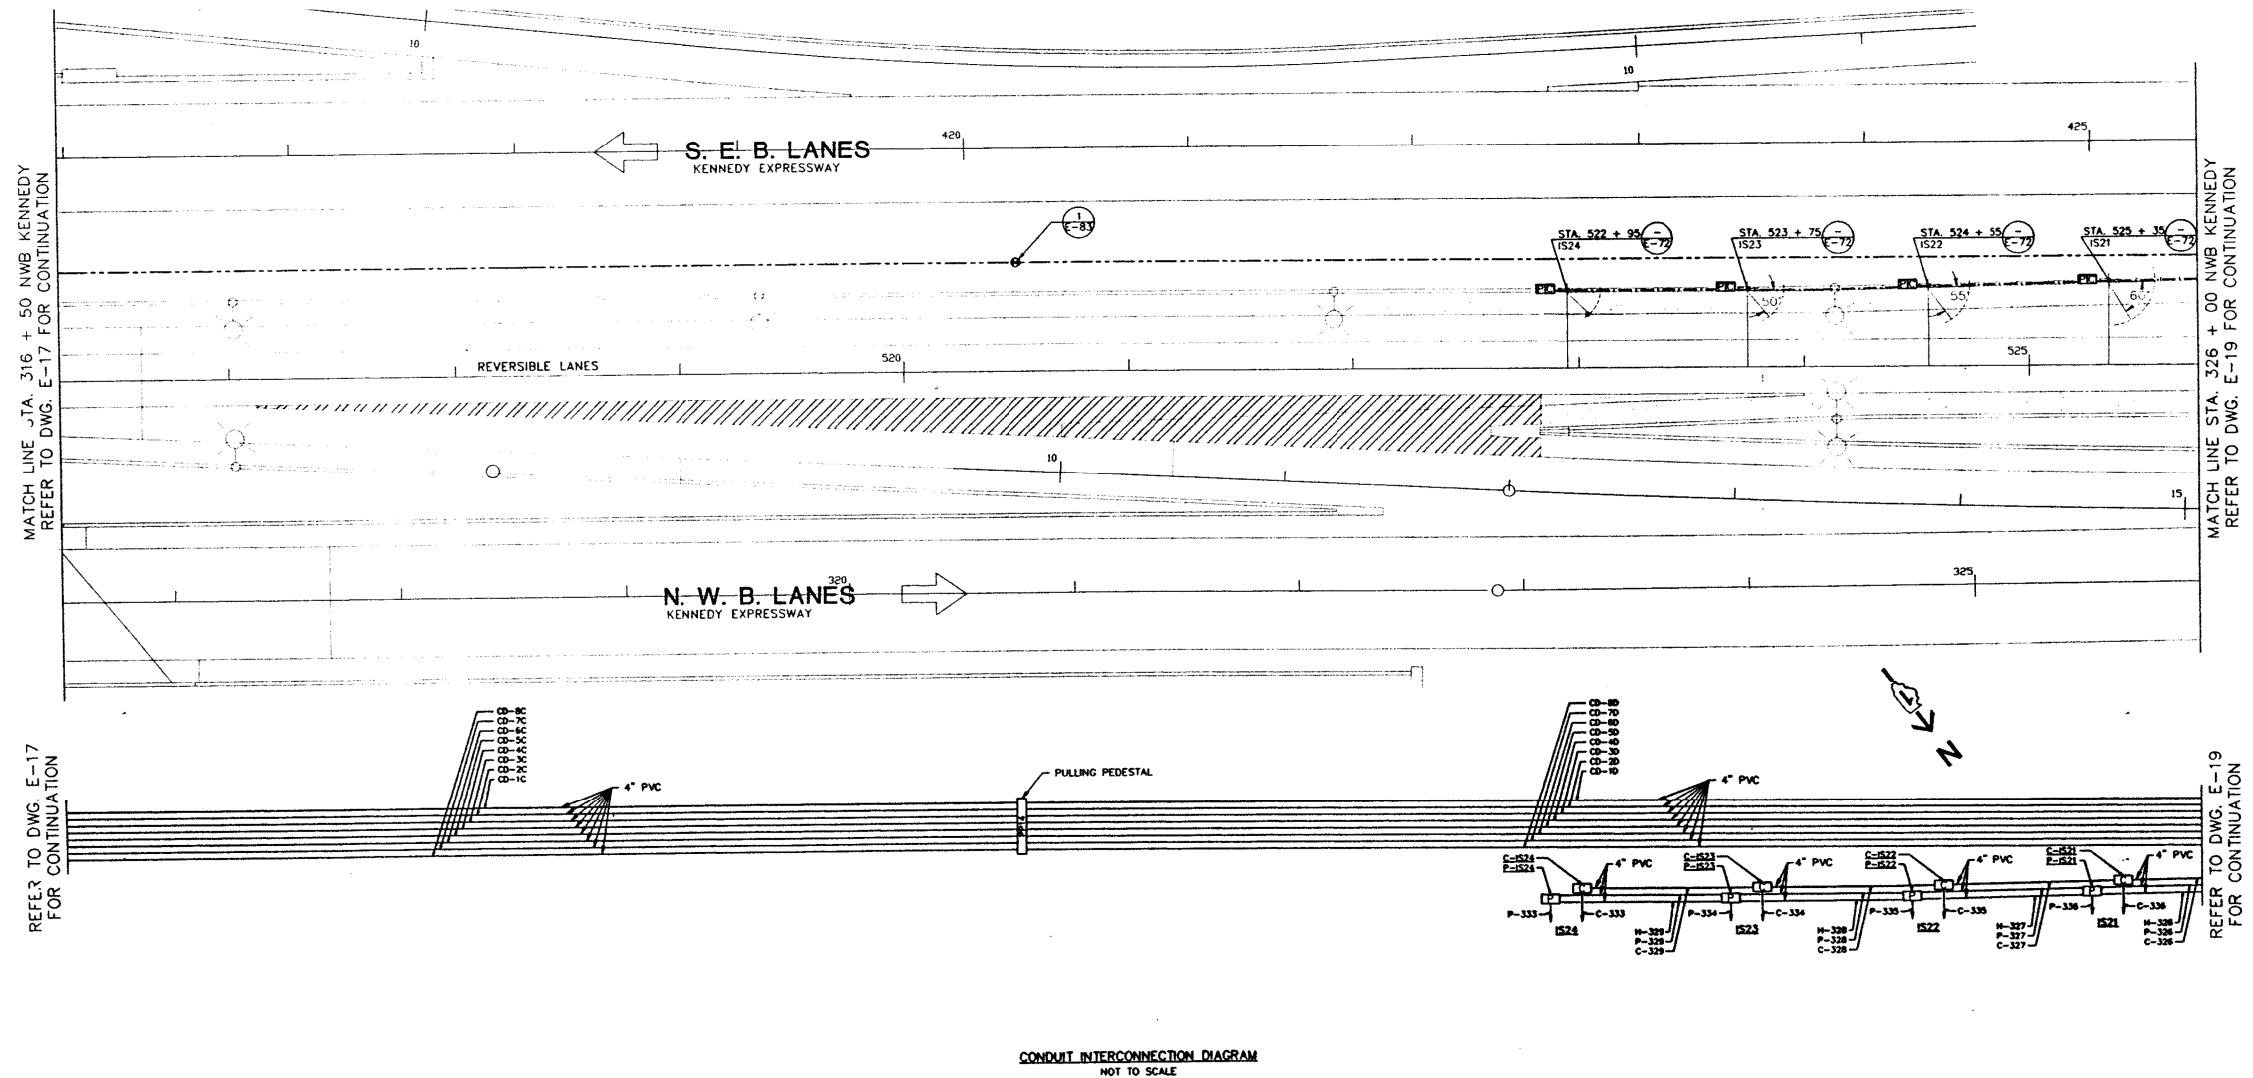

NOTES:

- 1.) SEE DWG. E-2 FOR GENERAL NOTES PERTAINING TO THIS DRAWING.
- 2.) CONDUIT & BORES IN BARRIER WALL ARE EXISTING (INSTALLED UNDER RIVCON CONTRACT).
- 3.) UNLESS OTHERWISE INDICATED, PROVIDE ALL CABLE & WIRE FOR WORK SHOWN ON THIS SHEET, REGARDLESS OF THE CONTRACT UNDER WHICH THE RACEWAY IS PROVIDED.
- 4.) UNLESS OTHERWISE INDICATED, CONDUIT & BORES NOT SHOWN WITHIN BOXED-OUT DASHED LINE IS EXISTING, OR WILL BE PROVIDED UNDER CONTRACT BY OTHERS.

NOTES:

1. THE ABOVE DRAWINGS REPRESENT AS LET DESIGN TO AID CONTRACTOR IN ASCERTAINING EXISTING CONDITIONS.
2. CONTRACTOR SHALL CONTACT IDOT D1 TO REQUEST THE MOST UP TO DATE RECORD DRAWINGS AVAILABLE AT THE TIME OF LETTING.

FOR INFORMATION ONLY

**SINGH**  
CONSULTING ENGINEERS  
www.singhinc.com

USER NAME = mgarvido  
FILE NAME = 150.D160T93-shr-details092  
PLOT SCALE = 2.000000:1.000000  
PLOT DATE = 06-MAY-2015 16:00

DESIGNED - DJ/AG  
DRAWN - DS/AS  
CHECKED - 1Y  
DATE - 5/6/2015

REVISED -  
REVISED -  
REVISED -  
REVISED -


STATE OF ILLINOIS  
DEPARTMENT OF TRANSPORTATION

INBOUND SLIP RAMP POWER & CONTROL PLAN

SCALE: NTS SHEET OF SHEETS STA. TO STA.

| F.A.I. RTE.               | SECTION   | COUNTY | TOTAL SHEETS | SHEET NO. |
|---------------------------|-----------|--------|--------------|-----------|
| 90/94                     | 2012-0521 | COOK   | 165          | 150       |
| CONTRACT NO. 60T93        |           |        |              |           |
| ILLINOIS FED. AID PROJECT |           |        |              |           |



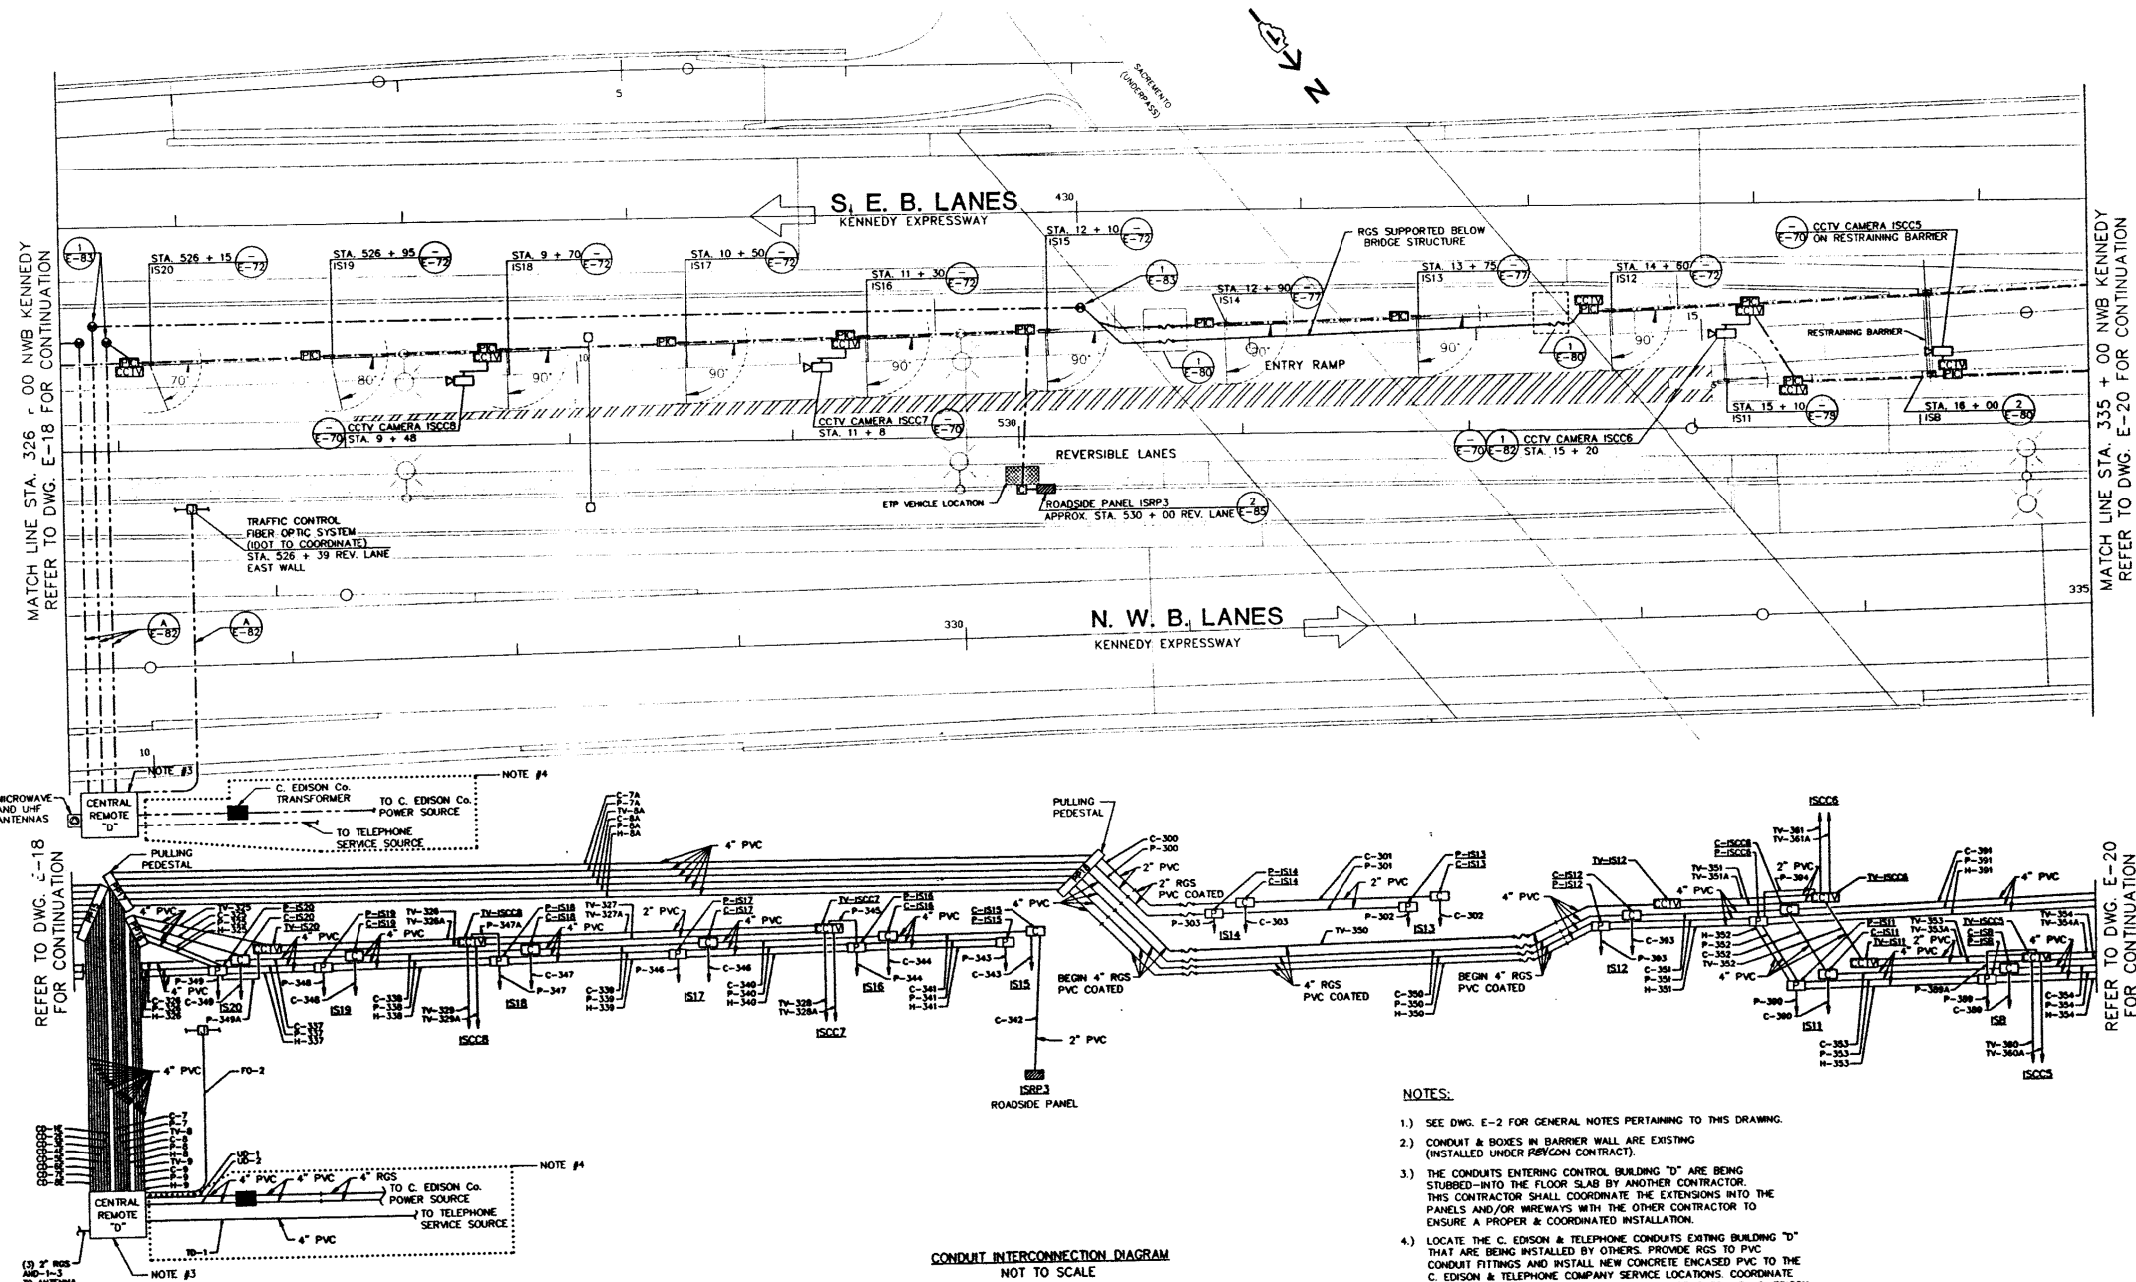

- NOTES:
1. THE ABOVE DRAWINGS REPRESENT AS LET DESIGN TO AID CONTRACTOR IN ASCERTAINING EXISTING CONDITIONS.
  2. CONTRACTOR SHALL CONTACT IDOT D1 TO REQUEST THE MOST UP TO DATE RECORD DRAWINGS AVAILABLE AT THE TIME OF LETTING.

FOR INFORMATION ONLY

**SINGH**  
CONSULTING ENGINEERS  
www.singhinc.com

|                                        |                  |           |
|----------------------------------------|------------------|-----------|
| USER NAME = mgarvida                   | DESIGNED - DJ/AG | REVISED - |
| FILE NAME = 151.D160T93-shr-details093 | DRAWN - DS/AS    | REVISED - |
| PLOT SCALE = 2.000000:1.000000         | CHECKED - 1Y     | REVISED - |
| PLOT DATE = 06-MAY-2015 16:01          | DATE - 5/6/2015  | REVISED - |


STATE OF ILLINOIS  
DEPARTMENT OF TRANSPORTATION

INBOUND SLIP RAMP POWER & CONTROL PLAN

SCALE: NTS SHEET OF SHEETS STA. TO STA.

|                           |                   |             |                  |               |
|---------------------------|-------------------|-------------|------------------|---------------|
| F.A.I. RTE. 90/94         | SECTION 2012-0521 | COUNTY COOK | TOTAL SHEETS 165 | SHEET NO. 151 |
| CONTRACT NO. 60T93        |                   |             |                  |               |
| ILLINOIS FED. AID PROJECT |                   |             |                  |               |



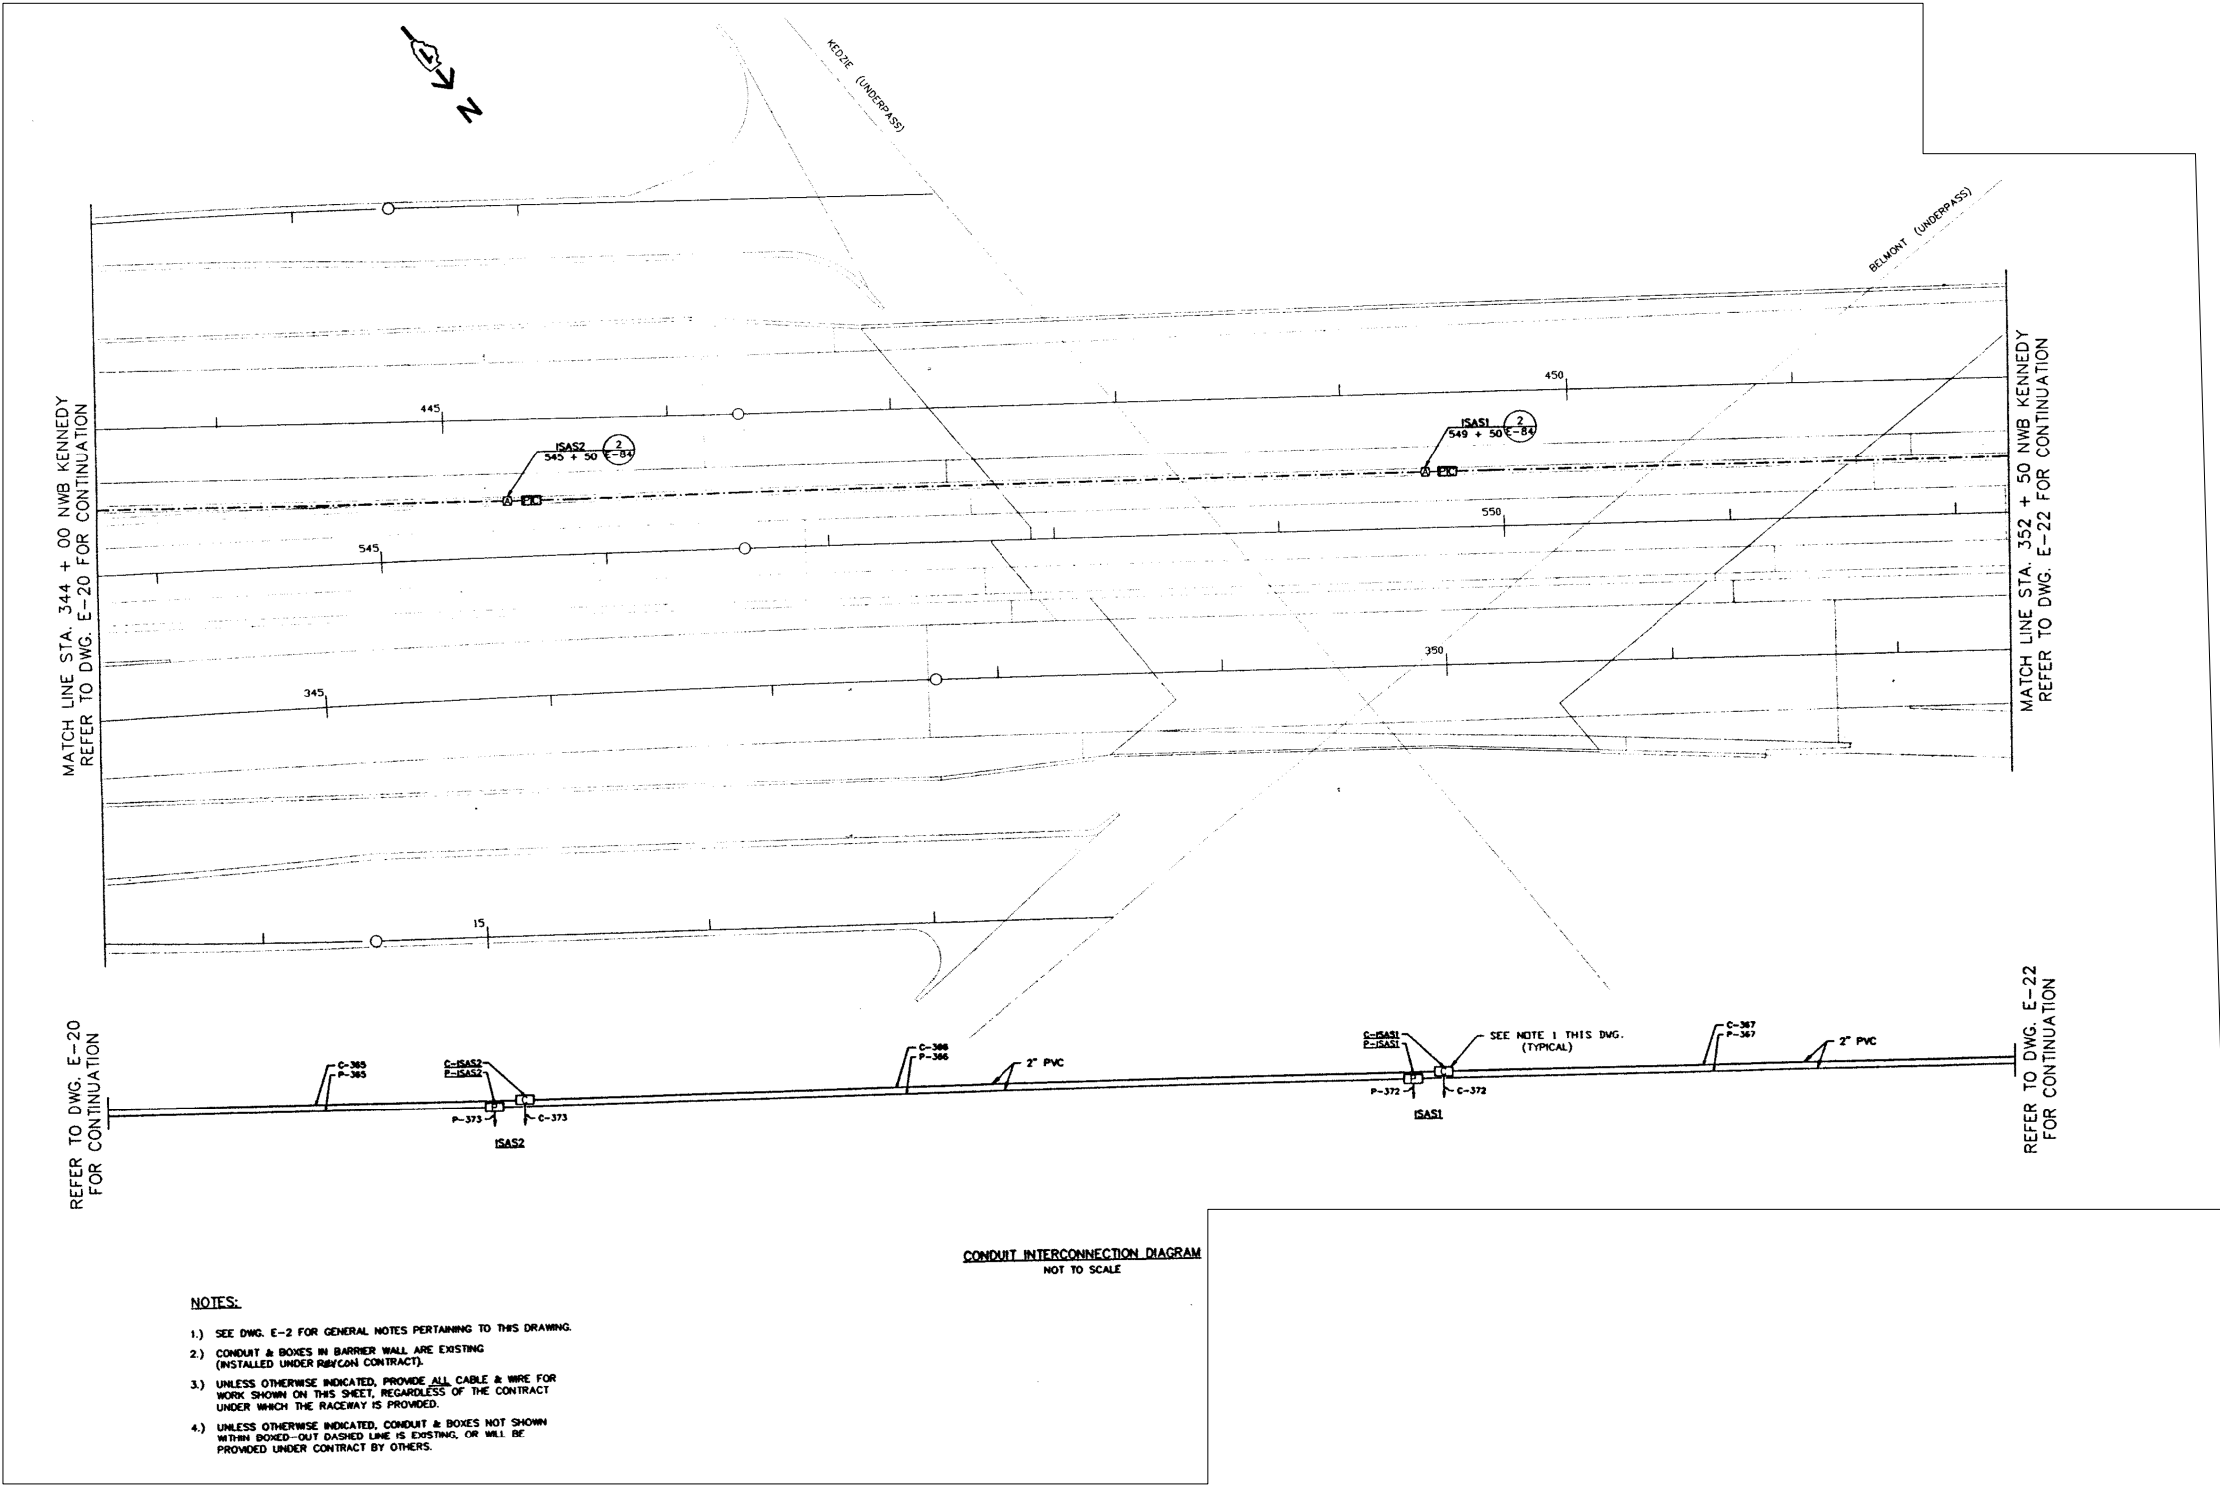

NOTES:

- 1.) SEE DWG. E-2 FOR GENERAL NOTES PERTAINING TO THIS DRAWING.
- 2.) CONDUIT & BOXES IN BARRIER WALL ARE EXISTING (INSTALLED UNDER RBYCON CONTRACT).
- 3.) UNLESS OTHERWISE INDICATED, PROVIDE ALL CABLE & WIRE FOR WORK SHOWN ON THIS SHEET, REGARDLESS OF THE CONTRACT UNDER WHICH THE RACEWAY IS PROVIDED.
- 4.) UNLESS OTHERWISE INDICATED, CONDUIT & BOXES NOT SHOWN WITHIN BOXED-OUT DASHED LINE IS EXISTING, OR WILL BE PROVIDED UNDER CONTRACT BY OTHERS.

NOTES:

1. THE ABOVE DRAWINGS REPRESENT AS LET DESIGN TO AID CONTRACTOR IN ASCERTAINING EXISTING CONDITIONS.
2. CONTRACTOR SHALL CONTACT IDOT D1 TO REQUEST THE MOST UP TO DATE RECORD DRAWINGS AVAILABLE AT THE TIME OF LETTING.

FOR INFORMATION ONLY

J:\293\Task-2\CON\CADD\_Sheet\53.D160T93-sh1-details095.dgn

**SINGH**  
CONSULTING ENGINEERS  
www.singhinc.com


|                                        |                  |           |
|----------------------------------------|------------------|-----------|
| USER NAME = mgarvada                   | DESIGNED - DJ/AG | REVISED - |
| FILE NAME = 153.D160T93-sh1-details095 | DRAWN - DS/AS    | REVISED - |
| PLOT SCALE = 2.000000:1.000000         | CHECKED - 1Y     | REVISED - |
| PLOT DATE = 06-MAY-2015 16:03          | DATE - 5/6/2015  | REVISED - |

STATE OF ILLINOIS  
DEPARTMENT OF TRANSPORTATION

INBOUND SLIP RAMP POWER & CONTROL PLAN

SCALE: NTS SHEET OF SHEETS STA. TO STA.

| F.A.I. RTE.               | SECTION   | COUNTY | TOTAL SHEETS | SHEET NO. |
|---------------------------|-----------|--------|--------------|-----------|
| 90/94                     | 2012-0521 | COOK   | 165          | 153       |
| CONTRACT NO. 60T93        |           |        |              |           |
| ILLINOIS FED. AID PROJECT |           |        |              |           |

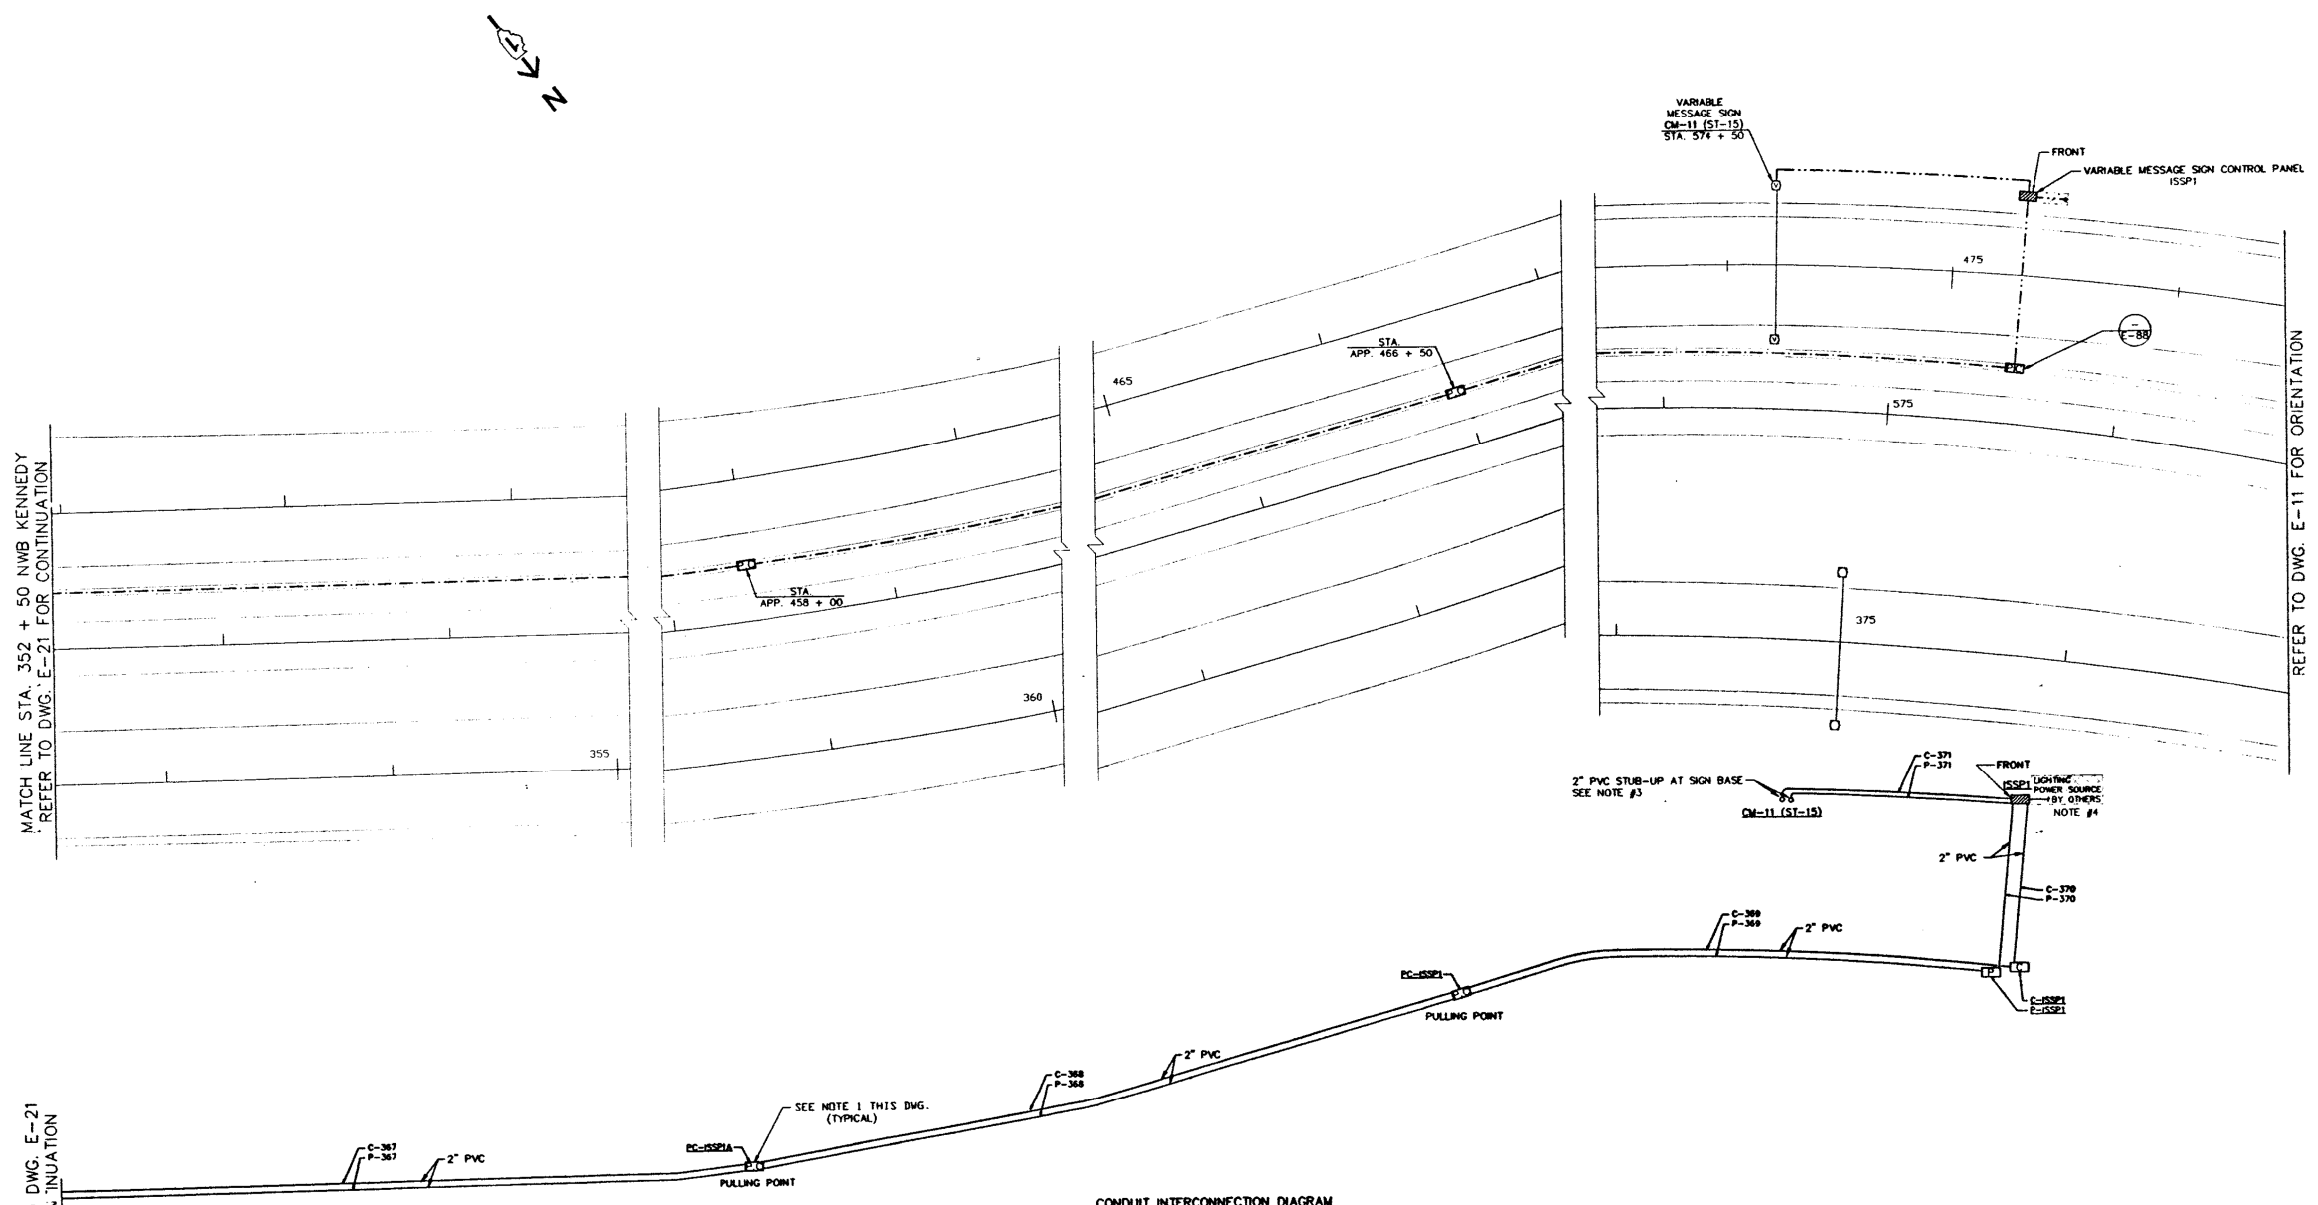

NOTES:

1. SEE DWG. E-2 FOR GENERAL NOTES PERTAINING TO THIS DRAWING.
2. CONDUIT & BOXES IN BARRIER WALL ARE EXISTING (INSTALLED UNDER R&B/C&N CONTRACT).
3. PROVIDE RGS CONDUIT TO PVC FITTING & ROUTE RGS CONDUIT UP TO VARIABLE MESSAGE SIGN (SEE DETAIL ON DWG. E-88).
4. PROVIDE CONCRETE PAD, CONTROL PANEL CONDUITS & WIRES AS SHOWN. COORDINATE THE INSTALLATION OF THE LIGHTING CIRCUIT (BY OTHERS) INTO THE CONTROL PANEL. (SEE DWG. E-88 FOR LIGHTING CIRCUIT CONDUIT IN PAD).
5. UNLESS OTHERWISE INDICATED, PROVIDE ALL CABLE & WIRE FOR WORK SHOWN ON THIS SHEET, REGARDLESS OF THE CONTRACT UNDER WHICH THE RACEWAY IS PROVIDED.
6. UNLESS OTHERWISE INDICATED, CONDUIT & BOXES NOT SHOWN WITHIN BOXED-OUT DASHED LINE IS EXISTING, OR WILL BE PROVIDED UNDER CONTRACT BY OTHERS.

NOTES:

1. THE ABOVE DRAWINGS REPRESENT AS LET DESIGN TO AID CONTRACTOR IN ASCERTAINING EXISTING CONDITIONS.
2. CONTRACTOR SHALL CONTACT IDOT D1 TO REQUEST THE MOST UP TO DATE RECORD DRAWINGS AVAILABLE AT THE TIME OF LETTING.

FOR INFORMATION ONLY

**SINGH**  
CONSULTING ENGINEERS  
www.singhinc.com


|                                        |                  |           |
|----------------------------------------|------------------|-----------|
| USER NAME = mgarvada                   | DESIGNED - DJ/AG | REVISED - |
| FILE NAME = 154.D160T93-shd-details096 | DRAWN - DS/AS    | REVISED - |
| PLOT SCALE = 2.000000:1.000000         | CHECKED - 1Y     | REVISED - |
| PLOT DATE = 06-MAY-2015 16:04          | DATE - 5/6/2015  | REVISED - |

STATE OF ILLINOIS  
DEPARTMENT OF TRANSPORTATION

INBOUND SLIP RAMP POWER & CONTROL PLAN

SCALE: NTS SHEET OF SHEETS STA. TO STA.

|                           |           |        |              |           |
|---------------------------|-----------|--------|--------------|-----------|
| F.A.I. RTE.               | SECTION   | COUNTY | TOTAL SHEETS | SHEET NO. |
| 90/94                     | 2012-0521 | COOK   | 165          | 154       |
| CONTRACT NO. 60T93        |           |        |              |           |
| ILLINOIS FED. AID PROJECT |           |        |              |           |

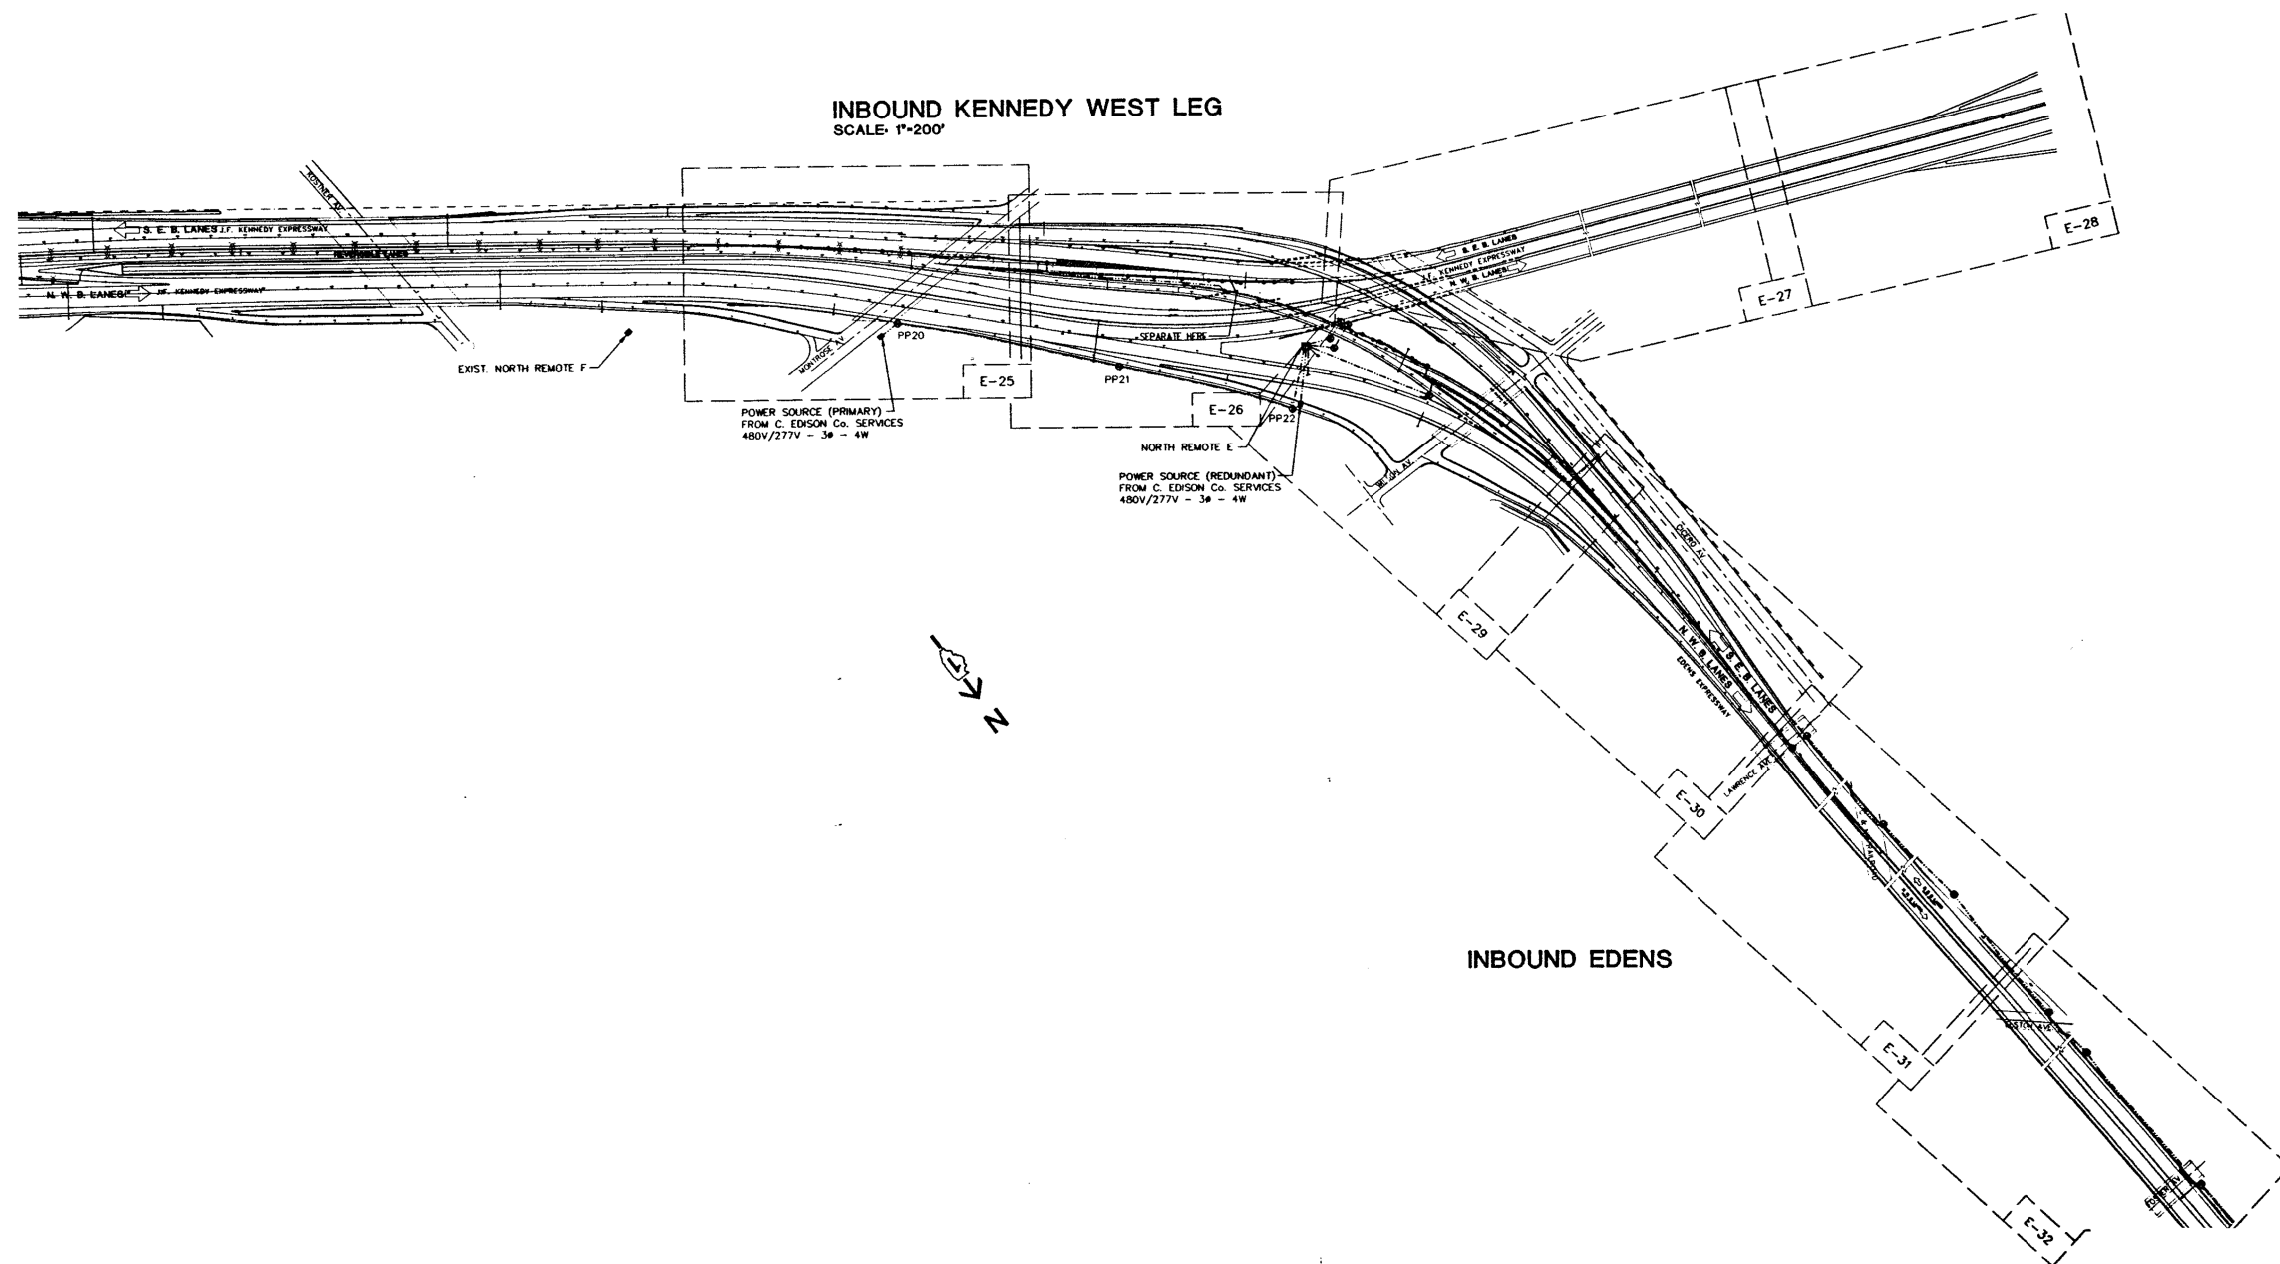

**NOTES:**

1. THE ABOVE DRAWINGS REPRESENT AS LET DESIGN TO AID CONTRACTOR IN ASCERTAINING EXISTING CONDITIONS.
2. CONTRACTOR SHALL CONTACT IDOT D1 TO REQUEST THE MOST UP TO DATE RECORD DRAWINGS AVAILABLE AT THE TIME OF LETTING.

**FOR INFORMATION ONLY**

**SINGH**  
CONSULTING ENGINEERS  
www.singhinc.com


|                                        |                  |           |
|----------------------------------------|------------------|-----------|
| USER NAME = mgarvido                   | DESIGNED - DJ/AG | REVISED - |
| FILE NAME = 155.D160T93-shd-details097 | DRAWN - DS/AS    | REVISED - |
| PLOT SCALE = 2.000000:1.000000         | CHECKED - 1Y     | REVISED - |
| PLOT DATE = 06-MAY-2015 16:05          | DATE - 5/6/2015  | REVISED - |

**STATE OF ILLINOIS**  
**DEPARTMENT OF TRANSPORTATION**

**INBOUND EDENS/KENNEDY ORIENTATION PLAN**

SCALE: NTS      SHEET      OF      SHEETS      STA.      TO STA.

| F.A.I. RTE.               | SECTION   | COUNTY | TOTAL SHEETS | SHEET NO. |
|---------------------------|-----------|--------|--------------|-----------|
| 90/94                     | 2012-0521 | COOK   | 165          | 155       |
| CONTRACT NO. 60T93        |           |        |              |           |
| ILLINOIS FED. AID PROJECT |           |        |              |           |

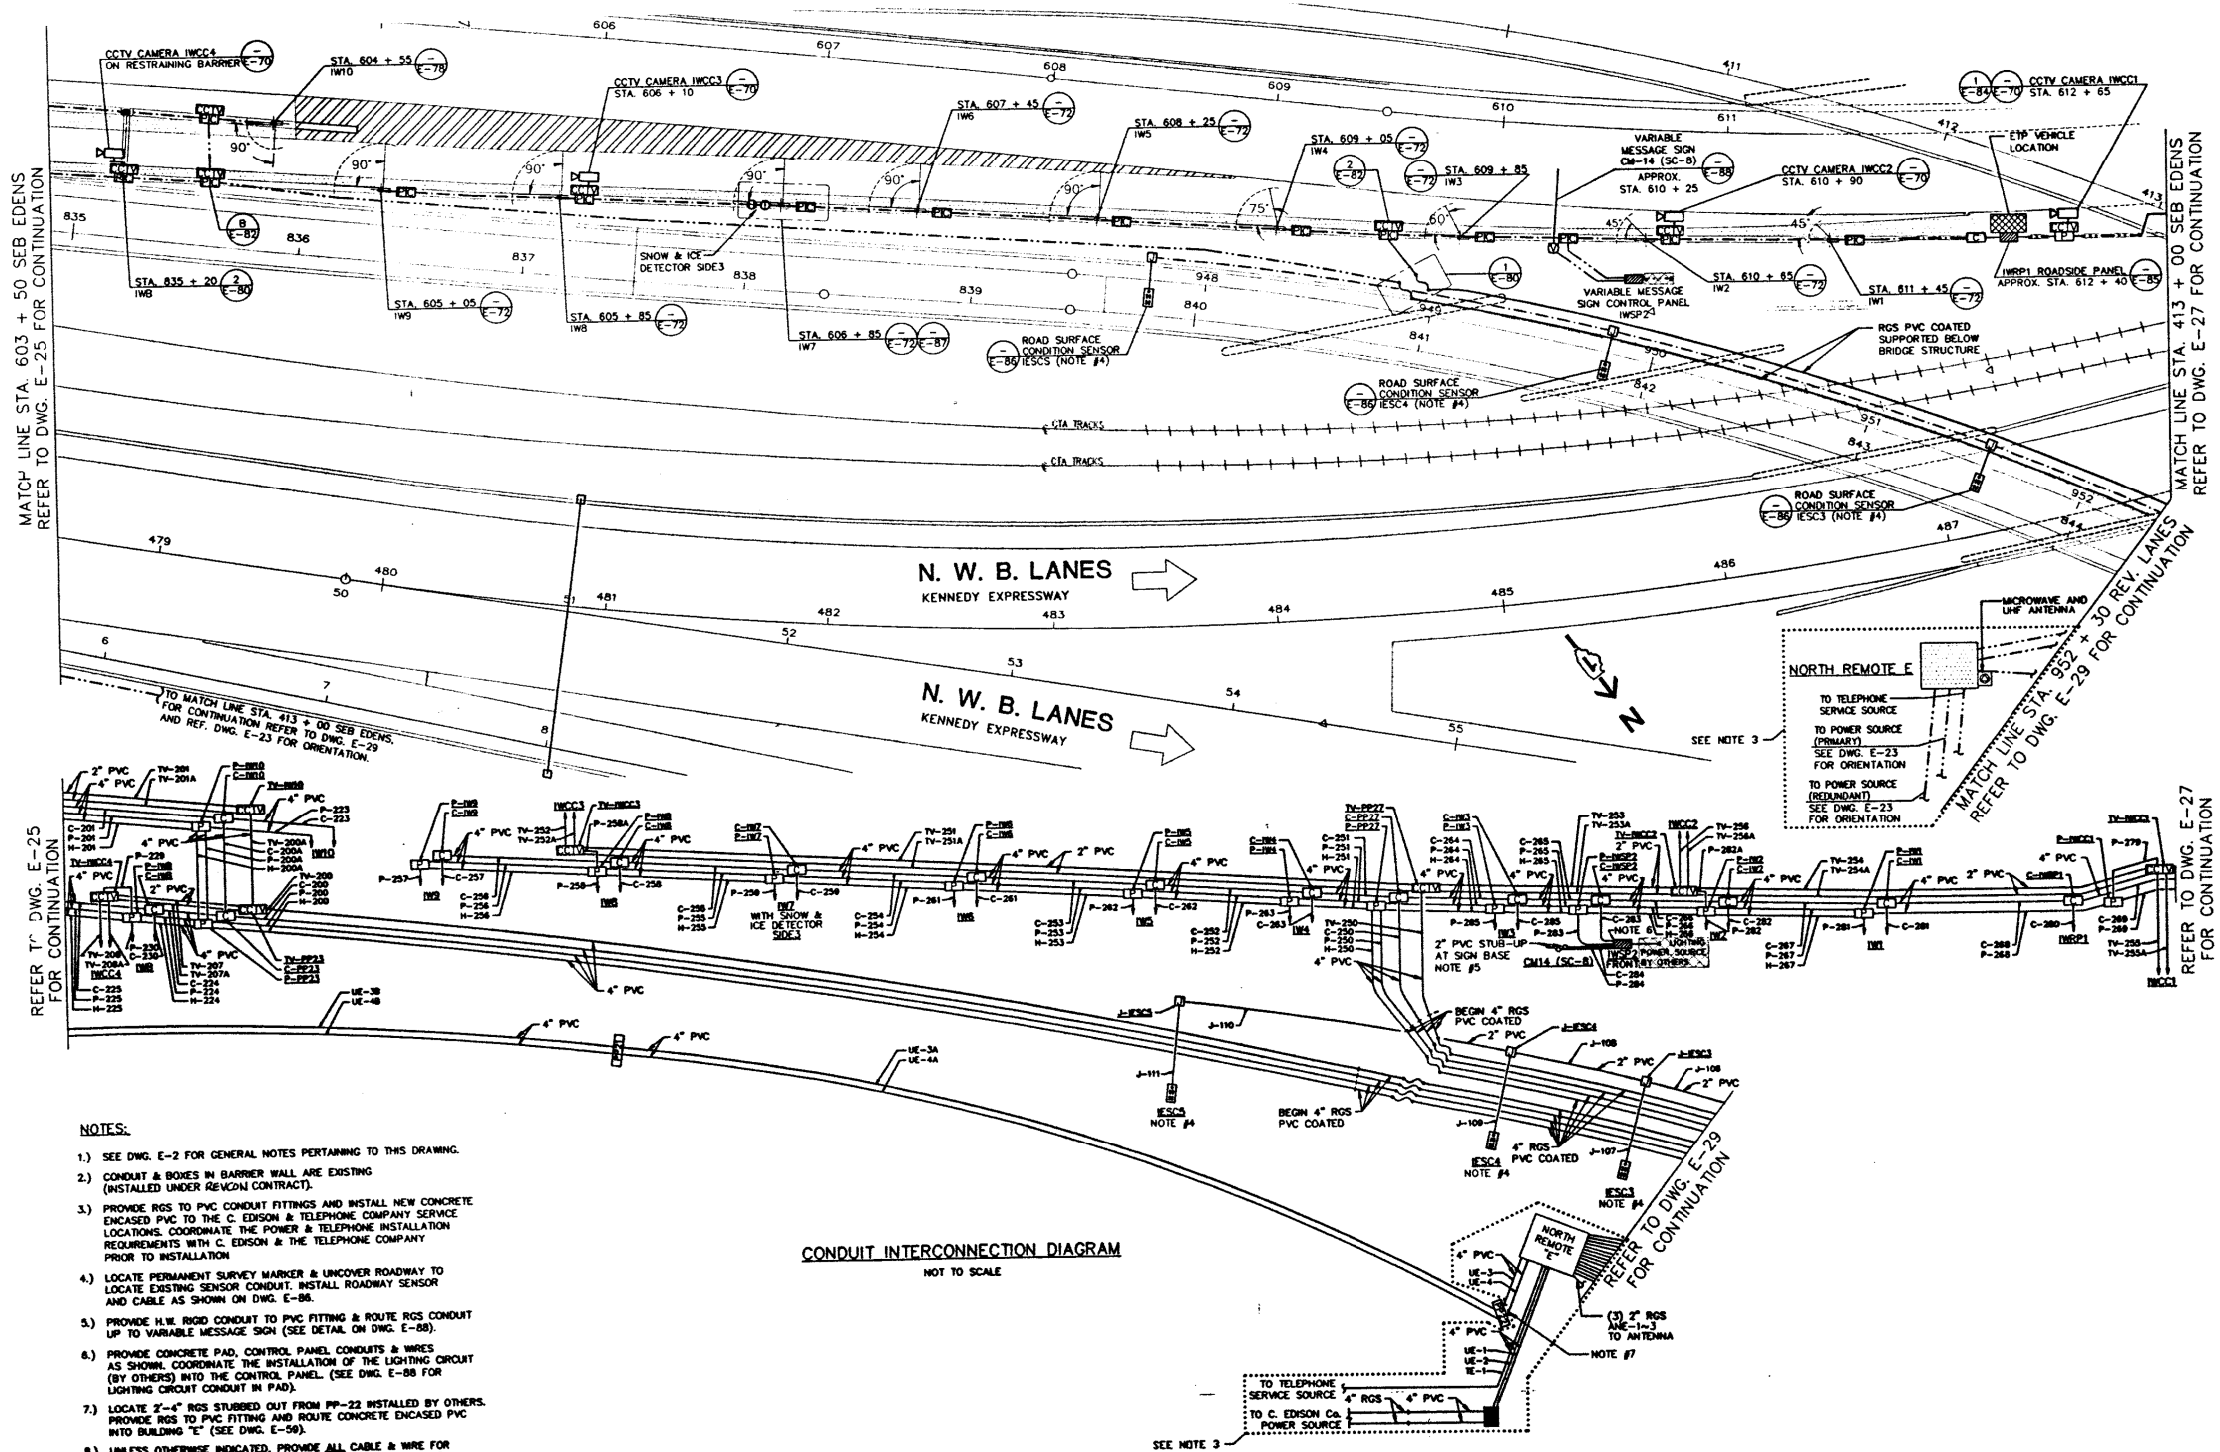

#### NOTES:

- SEE DWG. E-2 FOR GENERAL NOTES PERTAINING TO THIS DRAWING.
- CONDUIT & BOXES IN BARRIER WALL ARE EXISTING (INSTALLED UNDER REVCON CONTRACT).
- PROVIDE RGS TO PVC CONDUIT FITTINGS AND INSTALL NEW CONCRETE ENCASED PVC TO THE C. EDISON & TELEPHONE COMPANY SERVICE LOCATIONS. COORDINATE THE POWER & TELEPHONE INSTALLATION REQUIREMENTS WITH C. EDISON & THE TELEPHONE COMPANY PRIOR TO INSTALLATION.
- LOCATE PERMANENT SURVEY MARKER & UNCOVER ROADWAY TO LOCATE EXISTING SENSOR CONDUIT. INSTALL ROADWAY SENSOR AND CABLE AS SHOWN ON DWG. E-86.
- PROVIDE H.W. RIGID CONDUIT TO PVC FITTING & ROUTE RGS CONDUIT UP TO VARIABLE MESSAGE SIGN (SEE DETAIL ON DWG. E-88).
- PROVIDE CONCRETE PAD, CONTROL PANEL CONDUITS & WIRES AS SHOWN. COORDINATE THE INSTALLATION OF THE LIGHTING CIRCUIT (BY OTHERS) INTO THE CONTROL PANEL (SEE DWG. E-88 FOR LIGHTING CIRCUIT CONDUIT IN PAD).
- LOCATE 2"-4" RGS STUBBED OUT FROM PP-22 INSTALLED BY OTHERS. PROVIDE RGS TO PVC FITTING AND ROUTE CONCRETE ENCASED PVC INTO BUILDING "E" (SEE DWG. E-58).
- UNLESS OTHERWISE INDICATED, PROVIDE ALL CABLE & WIRE FOR WORK SHOWN ON THIS SHEET, REGARDLESS OF THE CONTRACT UNDER WHICH THE ROADWAY IS PROVIDED.
- UNLESS OTHERWISE INDICATED, CONDUIT & BOXES NOT SHOWN WITHIN BOXED-OUT DASHED LINE IS EXISTING, OR WILL BE PROVIDED UNDER CONTRACT BY OTHERS.

CONDUIT INTERCONNECTION DIAGRAM  
NOT TO SCALE

#### NOTES:

- THE ABOVE DRAWINGS REPRESENT AS LET DESIGN TO AID CONTRACTOR IN ASCERTAINING EXISTING CONDITIONS.
- CONTRACTOR SHALL CONTACT IDOT D1 TO REQUEST THE MOST UP TO DATE RECORD DRAWINGS AVAILABLE AT THE TIME OF LETTING.

**FOR INFORMATION ONLY**

**SINGH**  
CONSULTING ENGINEERS  
www.singhinc.com

USER NAME = mgarvida  
FILE NAME = 156.D160T93-shd-details098  
PLOT SCALE = 2.000000:1.000000  
PLOT DATE = 06-MAY-2015 16:05

DESIGNED - DJ/AG  
DRAWN - DS/AS  
CHECKED - 1Y  
DATE - 5/6/2015

REVISED -  
REVISED -  
REVISED -  
REVISED -


STATE OF ILLINOIS  
DEPARTMENT OF TRANSPORTATION

INBOUND KENNEDY POWER & CONTROL PLAN

SCALE: NTS SHEET OF SHEETS STA. TO STA.

|                           |           |        |              |           |
|---------------------------|-----------|--------|--------------|-----------|
| F.A.I. RTE.               | SECTION   | COUNTY | TOTAL SHEETS | SHEET NO. |
| 90/94                     | 2012-0521 | COOK   | 165          | 156       |
| CONTRACT NO. 60T93        |           |        |              |           |
| ILLINOIS FED. AID PROJECT |           |        |              |           |



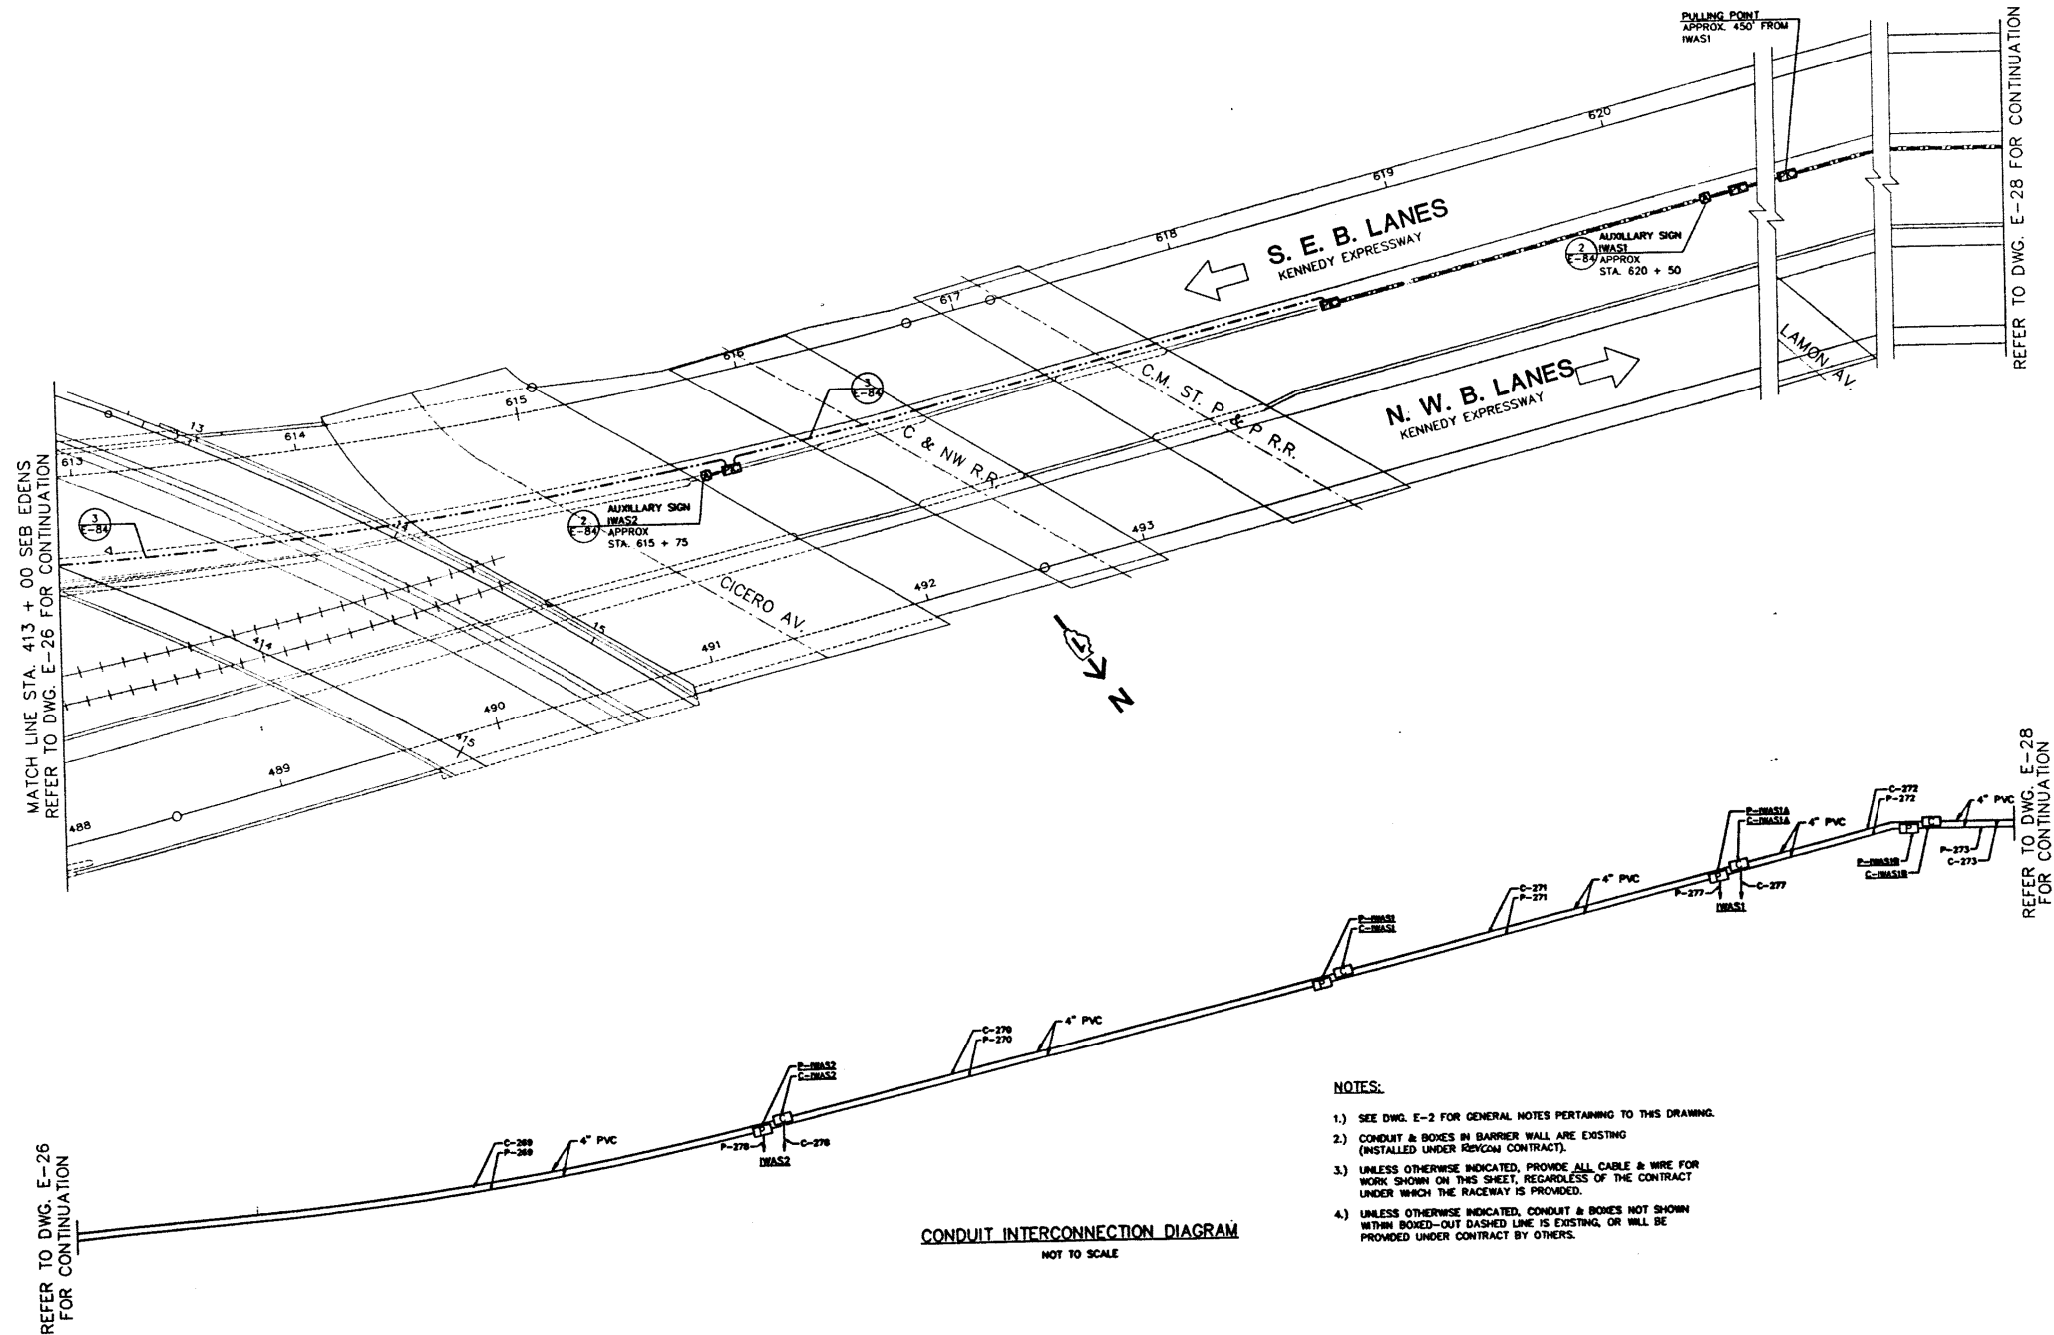

# NOTES:

- THE ABOVE DRAWINGS REPRESENT AS LET DESIGN TO AID CONTRACTOR IN ASCERTAINING EXISTING CONDITIONS.
- CONTRACTOR SHALL CONTACT IDOT D1 TO REQUEST THE MOST UP TO DATE RECORD DRAWINGS AVAILABLE AT THE TIME OF LETTING.

**FOR INFORMATION ONLY**

**SINGH**  
CONSULTING ENGINEERS  
www.singhinc.com


|                                        |                  |           |
|----------------------------------------|------------------|-----------|
| USER NAME = mgarvida                   | DESIGNED - DJ/AG | REVISED - |
| FILE NAME = 157.D160T93-shd-details099 | DRAWN - DS/AS    | REVISED - |
| PLOT SCALE = 2.000000:1.000000         | CHECKED - 1Y     | REVISED - |
| PLOT DATE = 06-MAY-2015 16:06          | DATE - 5/6/2015  | REVISED - |

STATE OF ILLINOIS  
DEPARTMENT OF TRANSPORTATION

INBOUND KENNEDY POWER & CONTROL PLAN

SCALE: NTS SHEET OF SHEETS STA. TO STA.

| F.A.I. RTE.               | SECTION   | COUNTY | TOTAL SHEETS | SHEET NO. |
|---------------------------|-----------|--------|--------------|-----------|
| 90/94                     | 2012-0521 | COOK   | 165          | 157       |
| CONTRACT NO. 60T93        |           |        |              |           |
| ILLINOIS FED. AID PROJECT |           |        |              |           |

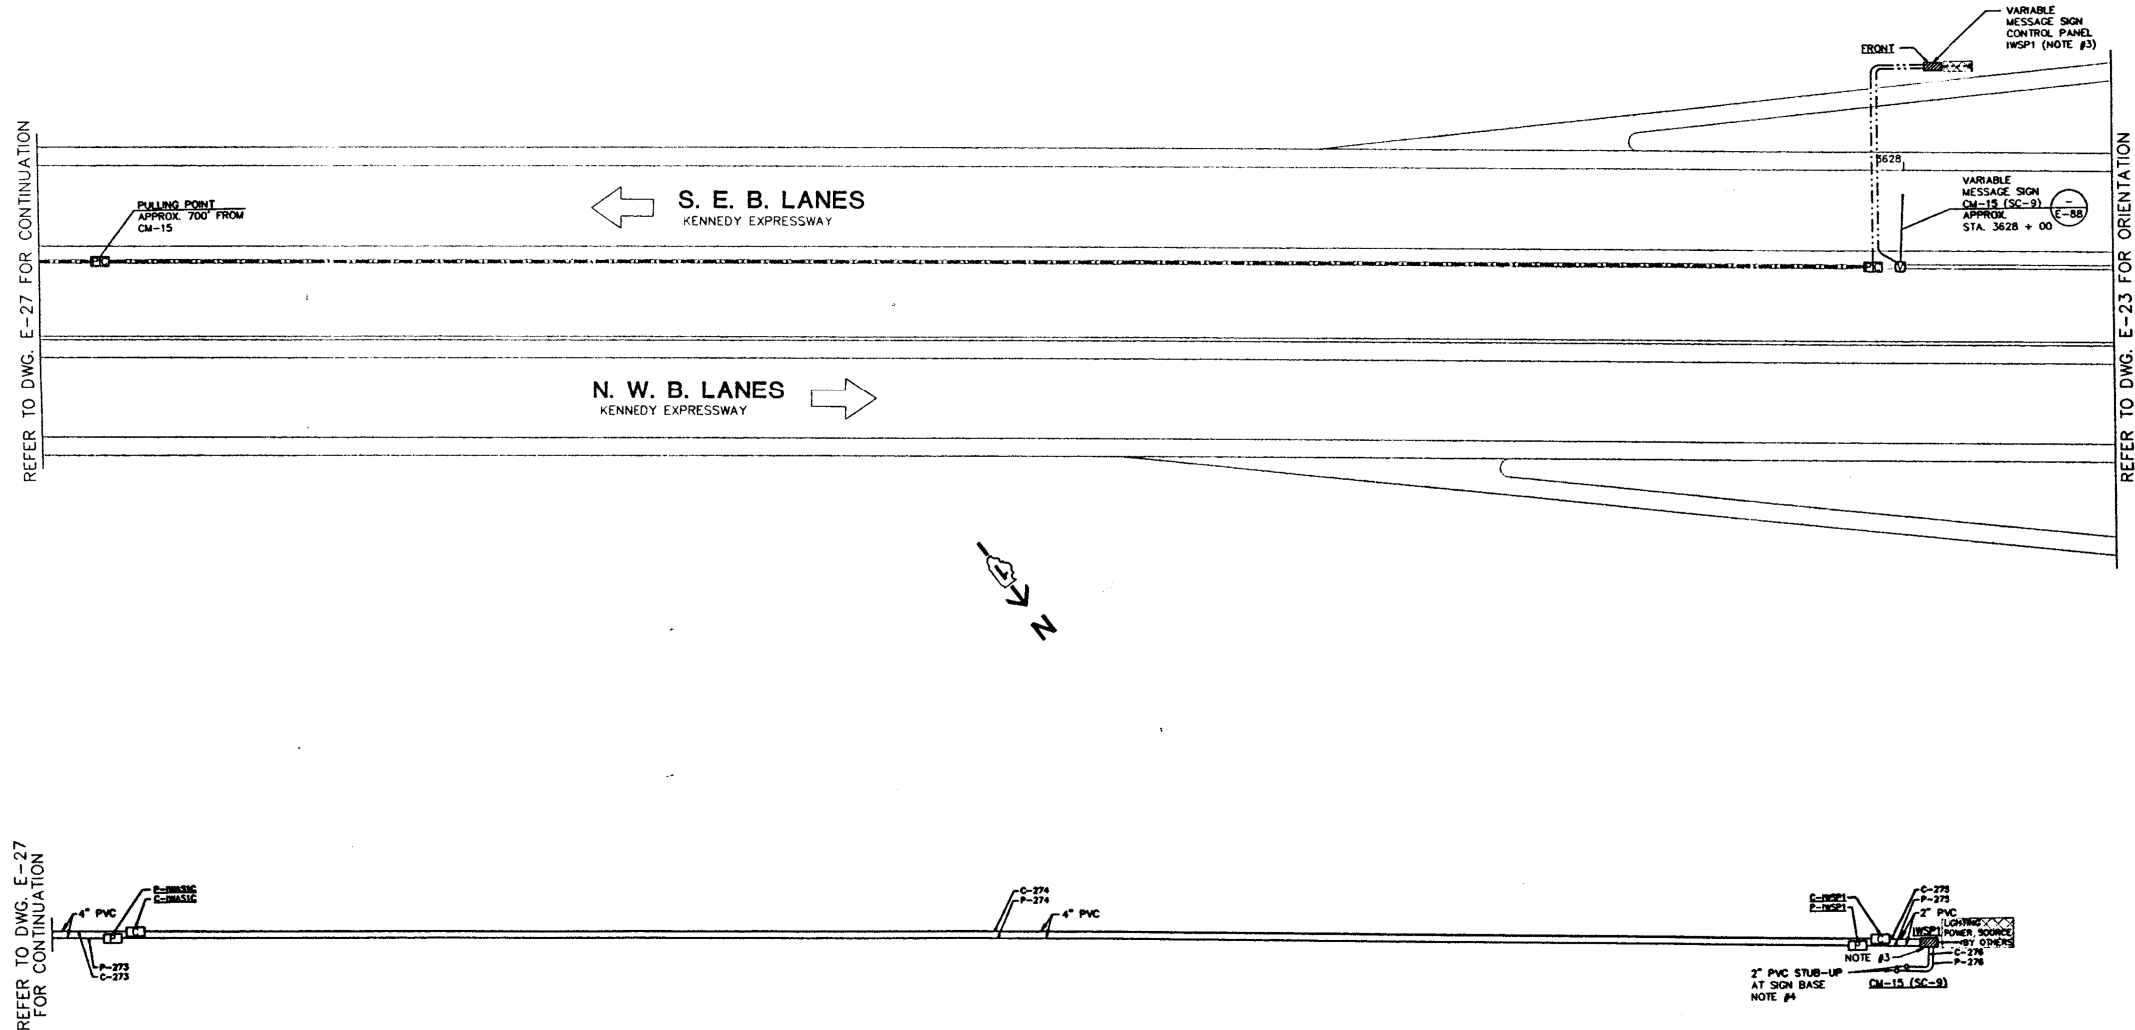

NOTES:

- 1.) SEE DWG. E-2 FOR GENERAL NOTES PERTAINING TO THIS DRAWING.
- 2.) CONDUIT & BOXES IN BARRIER WALL ARE EXISTING (INSTALLED UNDER REVENOM CONTRACT).
- 3.) PROVIDE CONCRETE PAD, CONTROL PANEL CONDUITS & WIRES AS SHOWN. COORDINATE THE INSTALLATION OF THE LIGHTING CIRCUIT (BY OTHERS) INTO THE CONTROL PANEL. (SEE DWG. E-88 FOR LIGHTING CIRCUIT CONDUIT IN PAD).
- 4.) PROVIDE PVC TO H.W. RIGID CONDUIT FITTINGS & ROUTE ROS CONDUITS UP TO VARIABLE MESSAGE SIGN-SEE DWG. E-86.
- 5.) UNLESS OTHERWISE INDICATED, PROVIDE ALL CABLE & WIRE FOR WORK SHOWN ON THIS SHEET, REGARDLESS OF THE CONTRACT UNDER WHICH THE RACEWAY IS PROVIDED.
- 6.) UNLESS OTHERWISE INDICATED, CONDUIT & BOXES NOT SHOWN WITHIN BOXED-OUT DASHED LINE IS EXISTING, OR WILL BE PROVIDED UNDER CONTRACT BY OTHERS.

NOTES:

1. THE ABOVE DRAWINGS REPRESENT AS LET DESIGN TO AID CONTRACTOR IN ASCERTAINING EXISTING CONDITIONS.
2. CONTRACTOR SHALL CONTACT IDOT D1 TO REQUEST THE MOST UP TO DATE RECORD DRAWINGS AVAILABLE AT THE TIME OF LETTING.

FOR INFORMATION ONLY

**SINGH**  
CONSULTING ENGINEERS  
www.singhinc.com

|                                        |                  |           |
|----------------------------------------|------------------|-----------|
| USER NAME = mgravido                   | DESIGNED - DJ/AG | REVISED - |
| FILE NAME = 158.D160T93-shd-details100 | DRAWN - DS/AS    | REVISED - |
| PLOT SCALE = 2.000000:1.000000         | CHECKED - 1Y     | REVISED - |
| PLOT DATE = 06-MAY-2015 16:07          | DATE - 5/6/2015  | REVISED - |


STATE OF ILLINOIS  
DEPARTMENT OF TRANSPORTATION

INBOUND KENNEDY POWER & CONTROL PLAN

SCALE: NTS SHEET OF SHEETS STA. TO STA.


| F.A.I. RTE.               | SECTION   | COUNTY | TOTAL SHEETS | SHEET NO. |
|---------------------------|-----------|--------|--------------|-----------|
| 90/94                     | 2012-0521 | COOK   | 165          | 158       |
| CONTRACT NO. 60T93        |           |        |              |           |
| ILLINOIS FED. AID PROJECT |           |        |              |           |



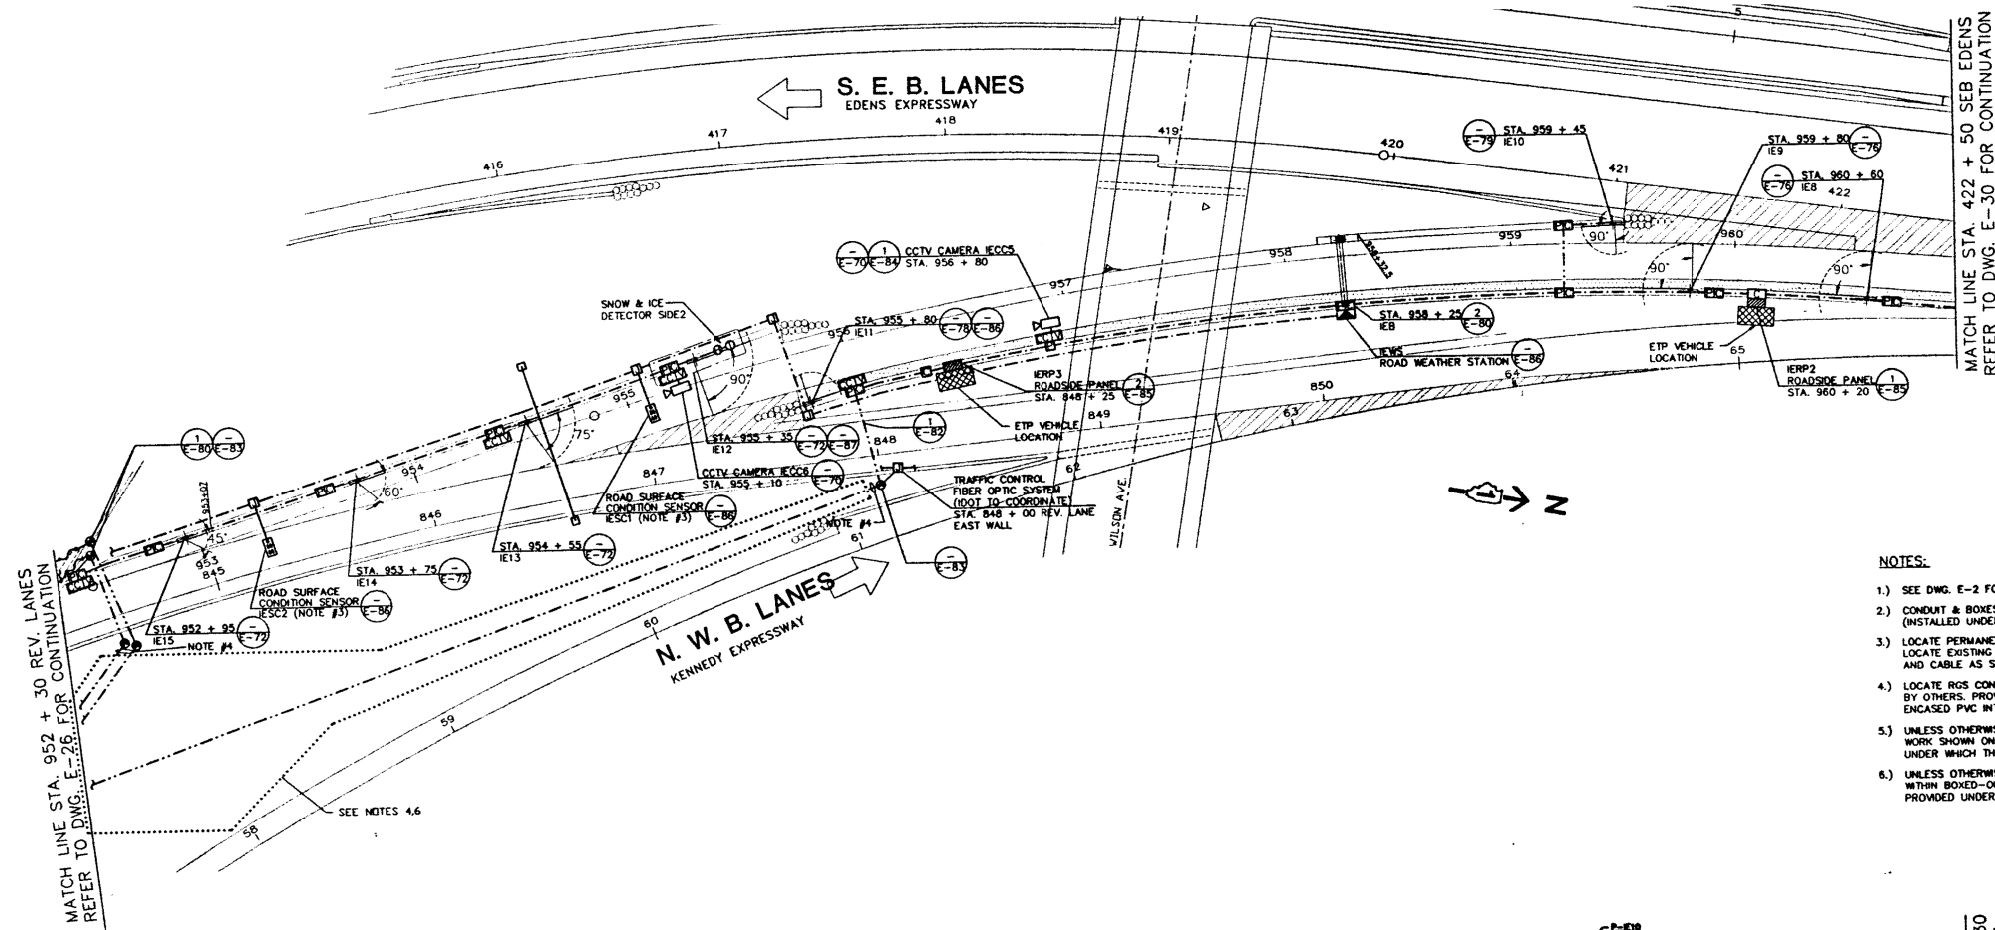

# NOTES:

- SEE DWG. E-2 FOR GENERAL NOTES PERTAINING TO THIS DRAWING.
- CONDUIT & BOXES IN BARRIER WALL ARE EXISTING (INSTALLED UNDER REVCOM CONTRACT).
- LOCATE PERMANENT SURVEY MARKER & UNCOVER ROADWAY TO LOCATE EXISTING SENSOR CONDUIT. INSTALL ROADWAY SENSOR AND CABLE AS SHOWN ON DWG. E-B6.
- LOCATE RGS CONDUITS STUBBED OUT FROM PULL BOX BY OTHERS. PROVIDE RGS TO PVC FITTING & ROUTE CONCRETE ENCASED PVC INTO BUILDING "T" (SEE DWG. E-59).
- UNLESS OTHERWISE INDICATED, PROVIDE ALL CABLE & WIRE FOR WORK SHOWN ON THIS SHEET, REGARDLESS OF THE CONTRACT UNDER WHICH THE RACEWAY IS PROVIDED.
- UNLESS OTHERWISE INDICATED, CONDUIT & BOXES NOT SHOWN WITHIN BOXED-OUT DASHED LINE IS EXISTING, OR WILL BE PROVIDED UNDER CONTRACT BY OTHERS.

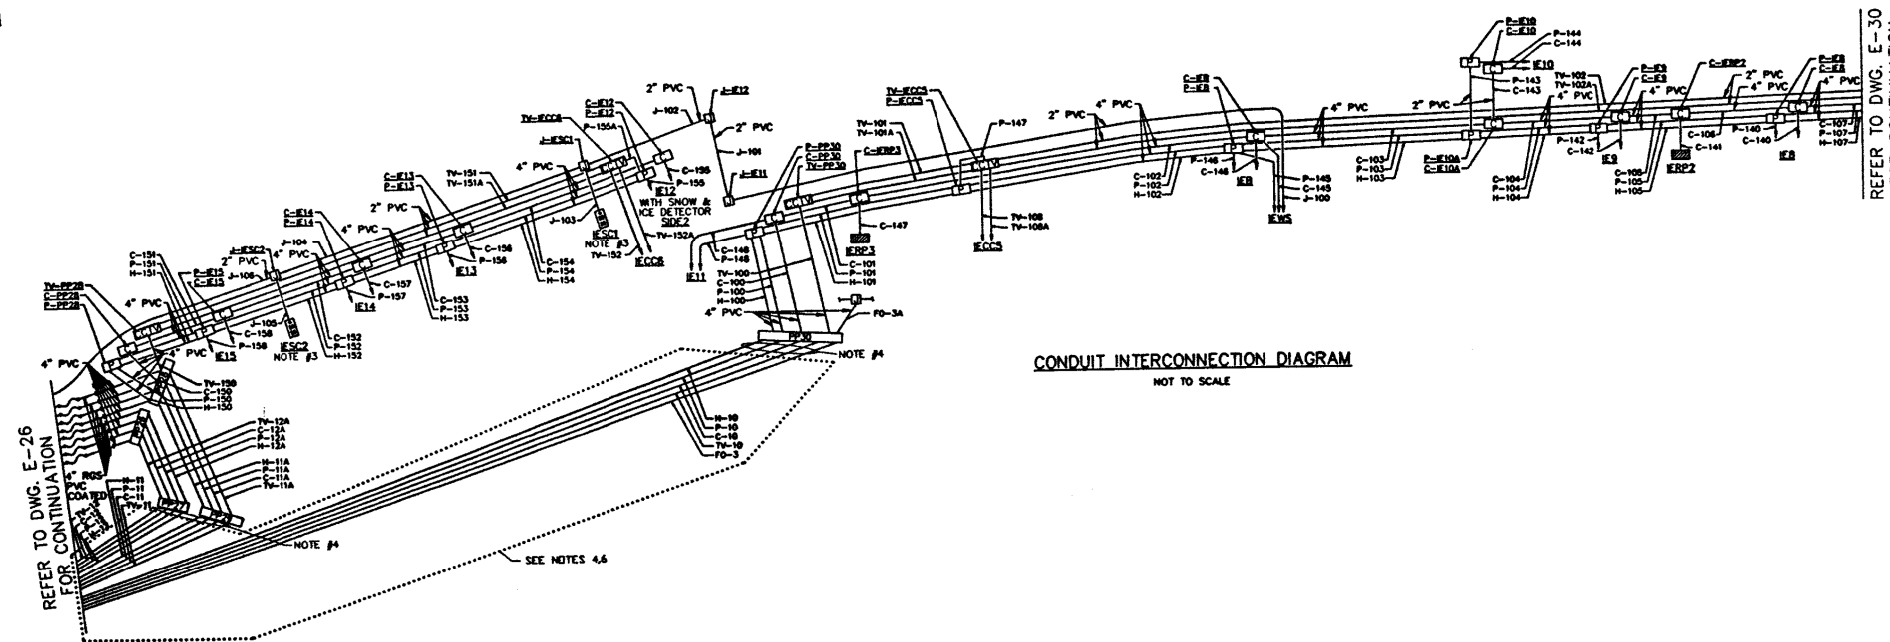

CONDUIT INTERCONNECTION DIAGRAM  
NOT TO SCALE

# NOTES:

- THE ABOVE DRAWINGS REPRESENT AS LET DESIGN TO AID CONTRACTOR IN ASCERTAINING EXISTING CONDITIONS.
- CONTRACTOR SHALL CONTACT IDOT D1 TO REQUEST THE MOST UP TO DATE RECORD DRAWINGS AVAILABLE AT THE TIME OF LETTING.

**FOR INFORMATION ONLY**

**SINGH**  
CONSULTING ENGINEERS  
www.singhinc.com

USER NAME = mgarvida  
FILE NAME = 159\_0160T93-shd-details101  
PLOT SCALE = 2.000000:1.000000  
PLOT DATE = 06-MAY-2015 16:08

DESIGNED - DJ/AG  
DRAWN - DS/AS  
CHECKED - 1Y  
DATE - 5/6/2015



REVISED -  
REVISED -  
REVISED -  
REVISED -

STATE OF ILLINOIS  
DEPARTMENT OF TRANSPORTATION

INBOUND EDENS POWER & CONTROL PLAN

SCALE: NTS SHEET OF SHEETS STA. TO STA.

| F.A.I. RTE.               | SECTION   | COUNTY | TOTAL SHEETS | SHEET NO. |
|---------------------------|-----------|--------|--------------|-----------|
| 90/94                     | 2012-0521 | COOK   | 165          | 159       |
| CONTRACT NO. 60T93        |           |        |              |           |
| ILLINOIS FED. AID PROJECT |           |        |              |           |

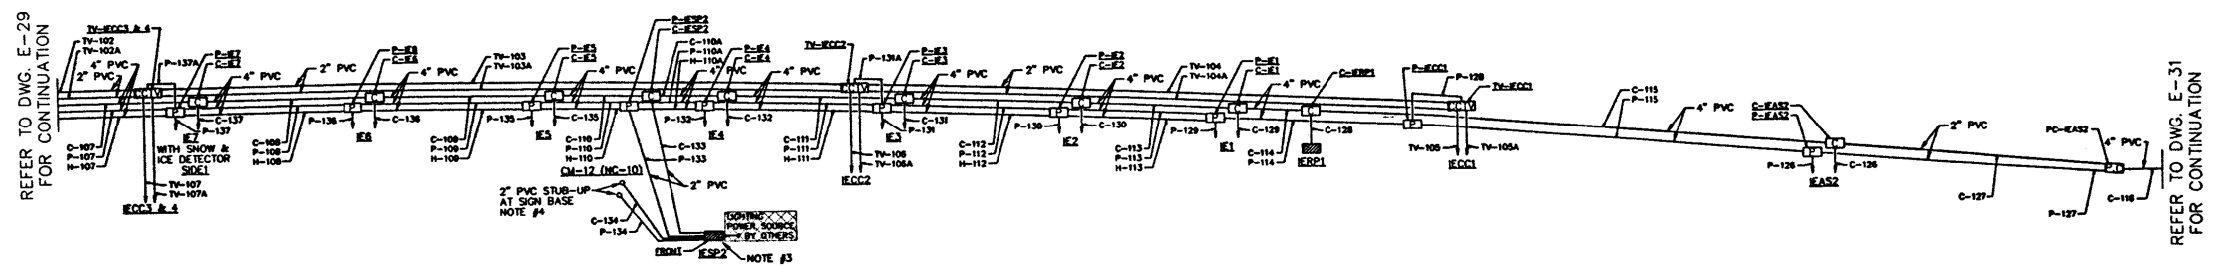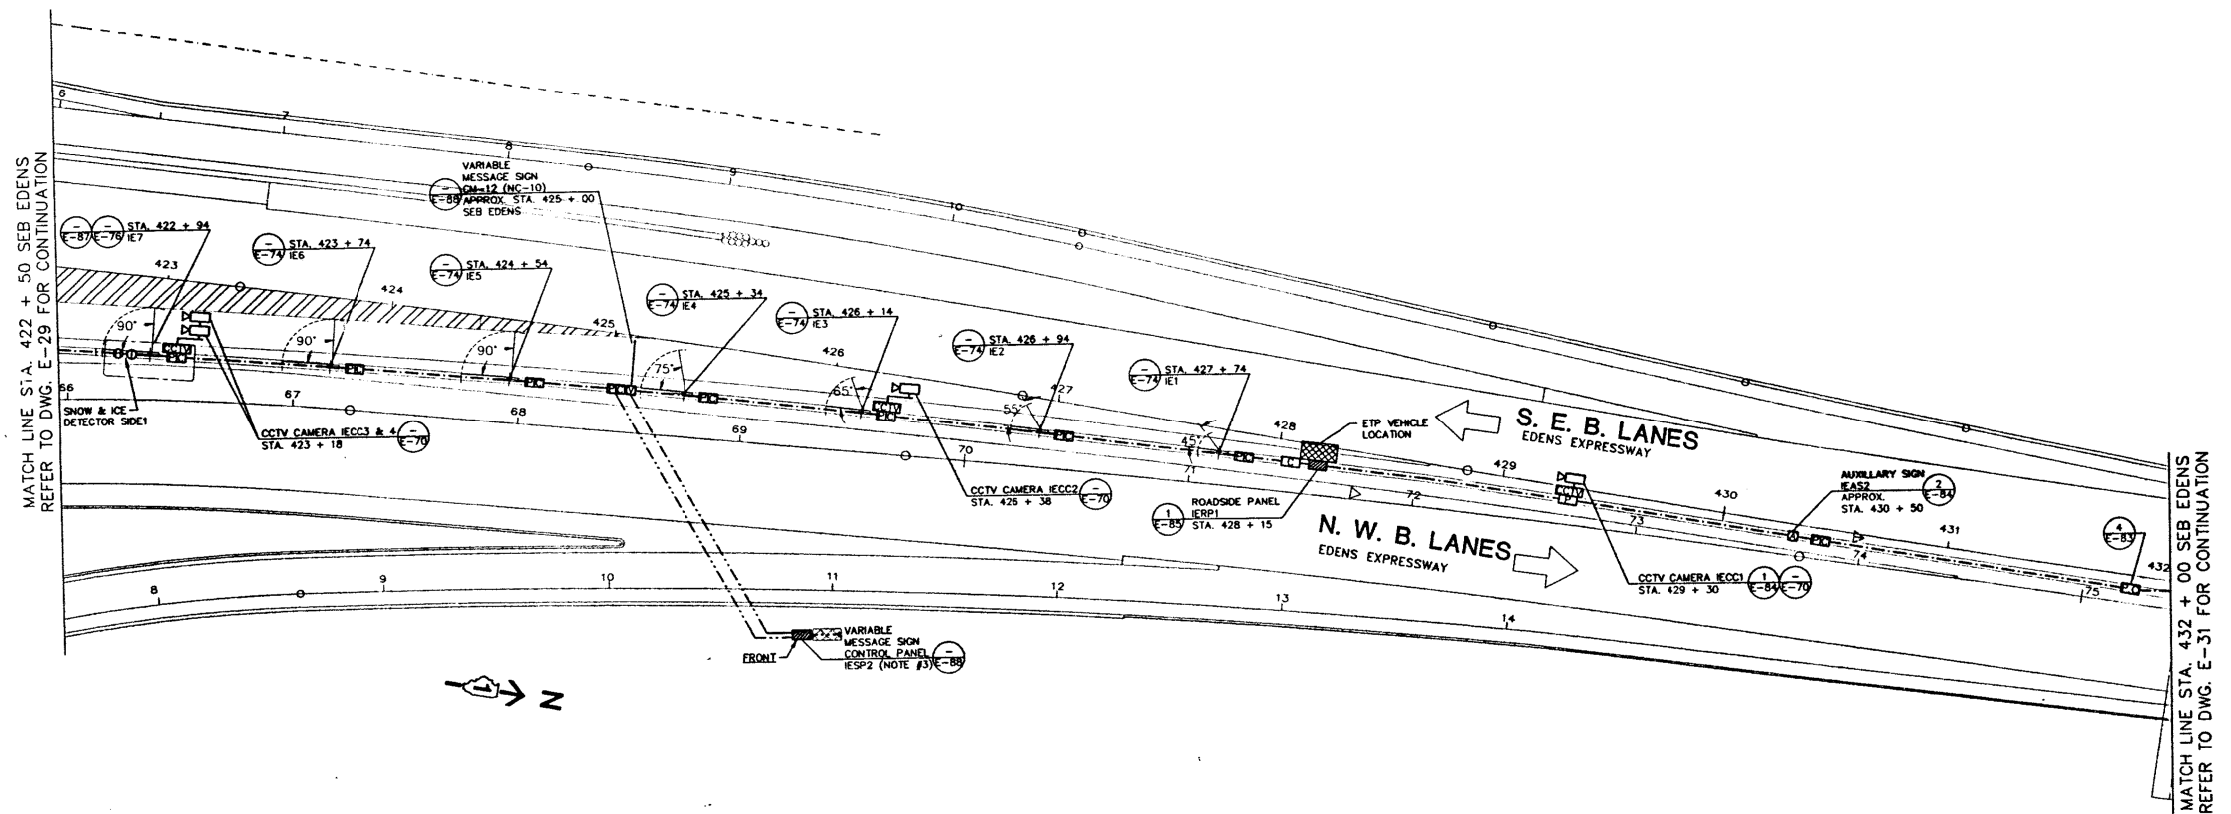

CONDUIT INTERCONNECTION DIAGRAM  
NOT TO SCALE

NOTES:

1. THE ABOVE DRAWINGS REPRESENT AS LET DESIGN TO AID CONTRACTOR IN ASCERTAINING EXISTING CONDITIONS.
2. CONTRACTOR SHALL CONTACT IDOT D1 TO REQUEST THE MOST UP TO DATE RECORD DRAWINGS AVAILABLE AT THE TIME OF LETTING.

**FOR INFORMATION ONLY**

**SINGH**  
CONSULTING ENGINEERS  
www.singhinc.com




|                                        |                  |           |
|----------------------------------------|------------------|-----------|
| USER NAME = mgarvido                   | DESIGNED - DJ/AG | REVISED - |
| FILE NAME = 160.D160T93-shd-details102 | DRAWN - DS/AS    | REVISED - |
| PLOT SCALE = 2.000000:1.000000         | CHECKED - 1Y     | REVISED - |
| PLOT DATE = 06-MAY-2015 16:09          | DATE - 5/6/2015  | REVISED - |

STATE OF ILLINOIS  
DEPARTMENT OF TRANSPORTATION

INBOUND EDENS POWER & CONTROL PLAN

SCALE: NTS SHEET OF SHEETS STA. TO STA.

| F.A.I. RTE.               | SECTION   | COUNTY | TOTAL SHEETS | SHEET NO. |
|---------------------------|-----------|--------|--------------|-----------|
| 90/94                     | 2012-0521 | COOK   | 165          | 160       |
| CONTRACT NO. 60T93        |           |        |              |           |
| ILLINOIS FED. AID PROJECT |           |        |              |           |

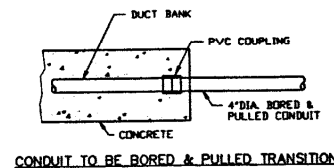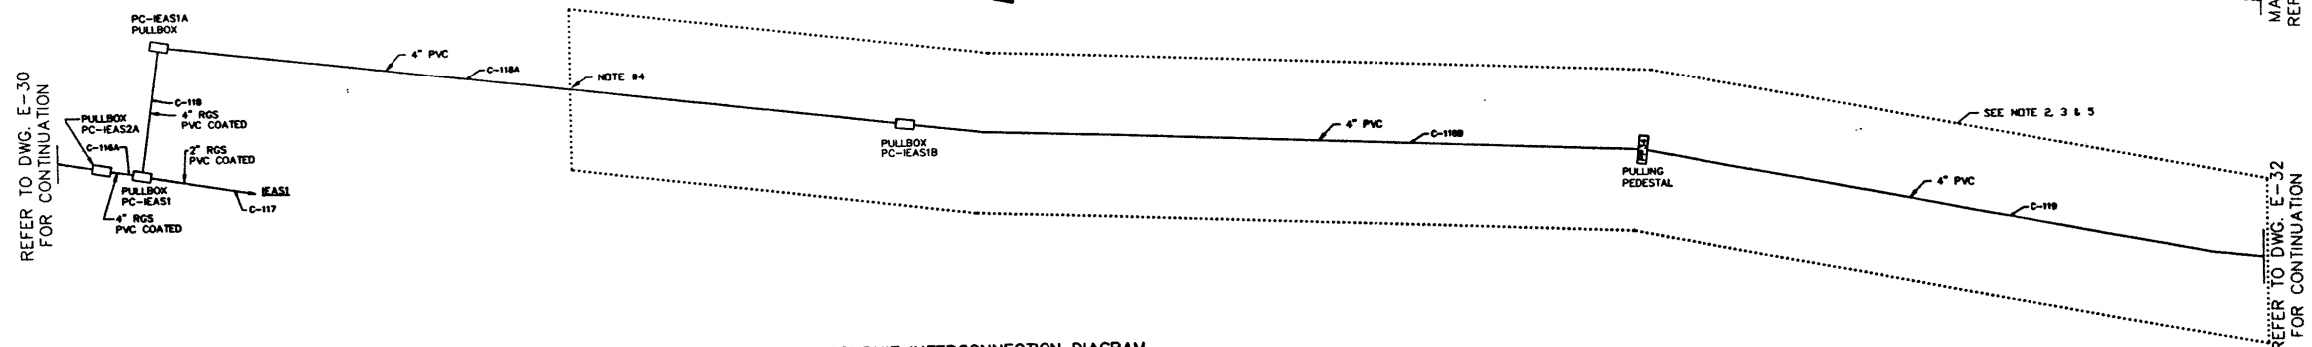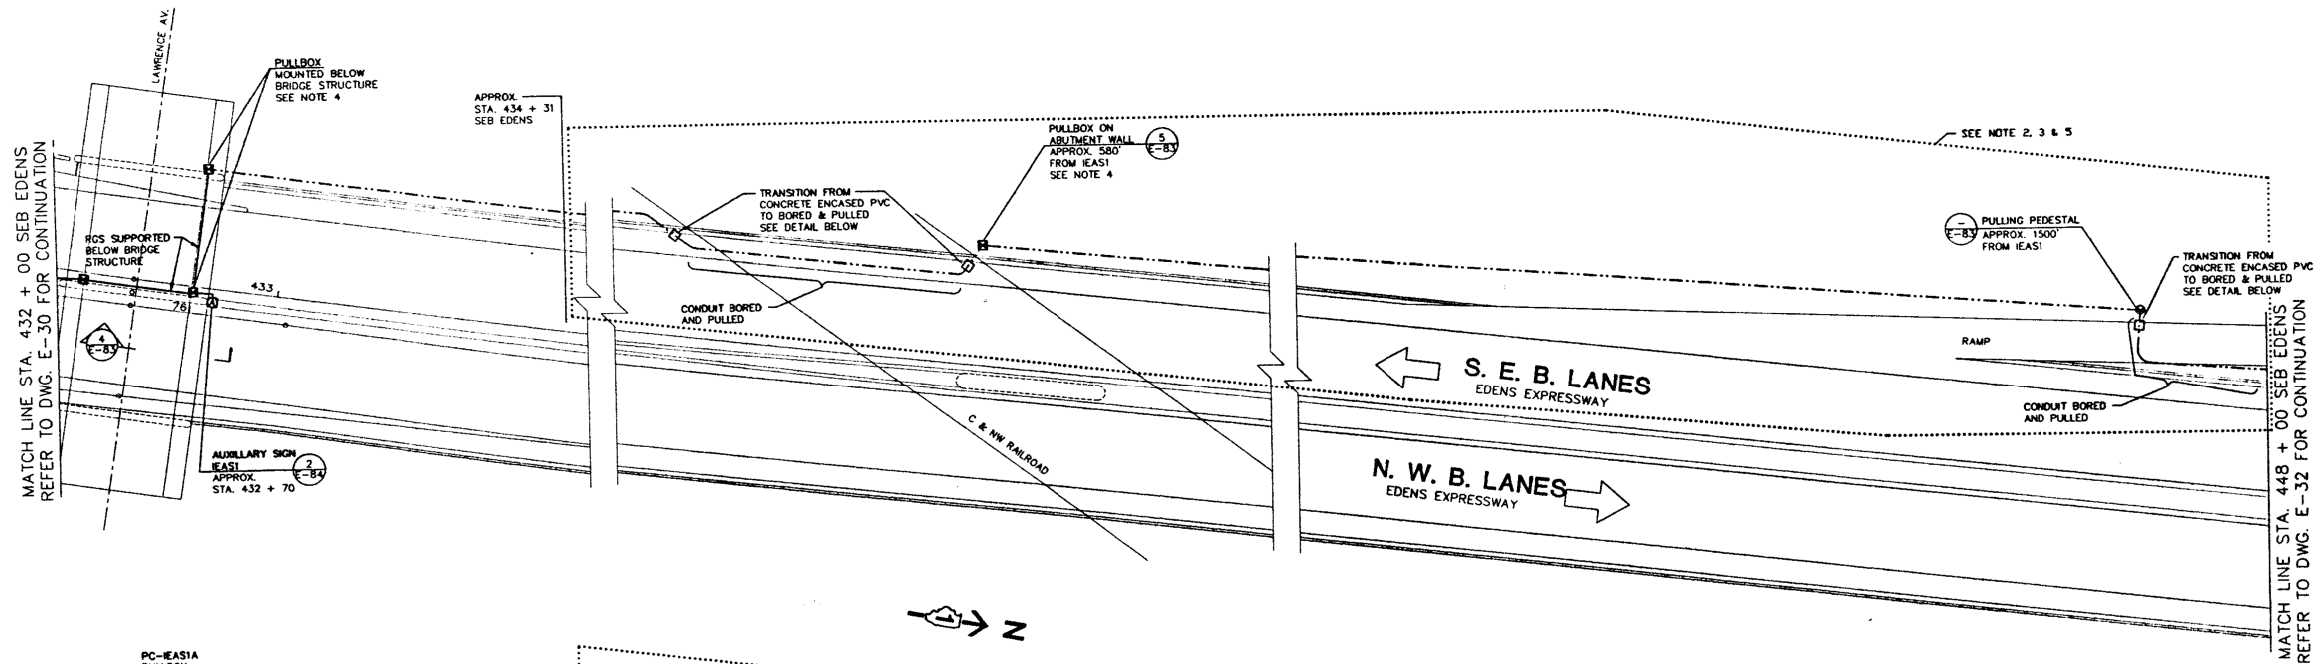

#### NOTES:

- 1.) SEE DWG. E-2 FOR GENERAL NOTES PERTAINING TO THIS DRAWING.
- 2.) UNLESS OTHERWISE INDICATED, PROVIDE ALL CABLE & WIRE FOR WORK SHOWN ON THIS SHEET, REGARDLESS OF THE CONTRACT UNDER WHICH THE RACEWAY IS PROVIDED.
- 3.) UNLESS OTHERWISE INDICATED, CONDUIT & BOXES NOT SHOWN WITHIN BOXED-OUT DASHED LINE IS EXISTING, OR WILL BE PROVIDED UNDER CONTRACT BY OTHERS.
- 4.) LOCATE EXISTING CONCRETE ENCASED PVC INSTALLED BY OTHERS. PROVIDE PVC FITTING & CONTINUE CONCRETE ENCASED PVC AS SHOWN.
- 5.) LOCATE PULLING PEDESTAL A MINIMUM OF 8'-0" FROM EDGE OF ROAD, OR AS DIRECTED BY THE ENGINEER.

#### NOTES:

1. THE ABOVE DRAWINGS REPRESENT AS LET DESIGN TO AID CONTRACTOR IN ASCERTAINING EXISTING CONDITIONS.
2. CONTRACTOR SHALL CONTACT IDOT D1 TO REQUEST THE MOST UP TO DATE RECORD DRAWINGS AVAILABLE AT THE TIME OF LETTING.

**FOR INFORMATION ONLY**

**SINGH**  
CONSULTING ENGINEERS  
www.singhinc.com


|                                       |                  |           |
|---------------------------------------|------------------|-----------|
| USER NAME = mgarvada                  | DESIGNED - DJ/AG | REVISED - |
| FILE NAME = 161.D160T93-sht-details03 | DRAWN - DS/AS    | REVISED - |
| PLOT SCALE = 2.000000:1.000000        | CHECKED - 1Y     | REVISED - |
| PLOT DATE = 06-MAY-2015 16:10         | DATE - 5/6/2015  | REVISED - |

STATE OF ILLINOIS  
DEPARTMENT OF TRANSPORTATION

INBOUND EDENS POWER & CONTROL PLAN

SCALE: NTS SHEET OF SHEETS STA. TO STA.

| F.A.I. RTE.               | SECTION   | COUNTY | TOTAL SHEETS | SHEET NO. |
|---------------------------|-----------|--------|--------------|-----------|
| 90/94                     | 2012-0521 | COOK   | 165          | 161       |
| CONTRACT NO. 60T93        |           |        |              |           |
| ILLINOIS FED. AID PROJECT |           |        |              |           |

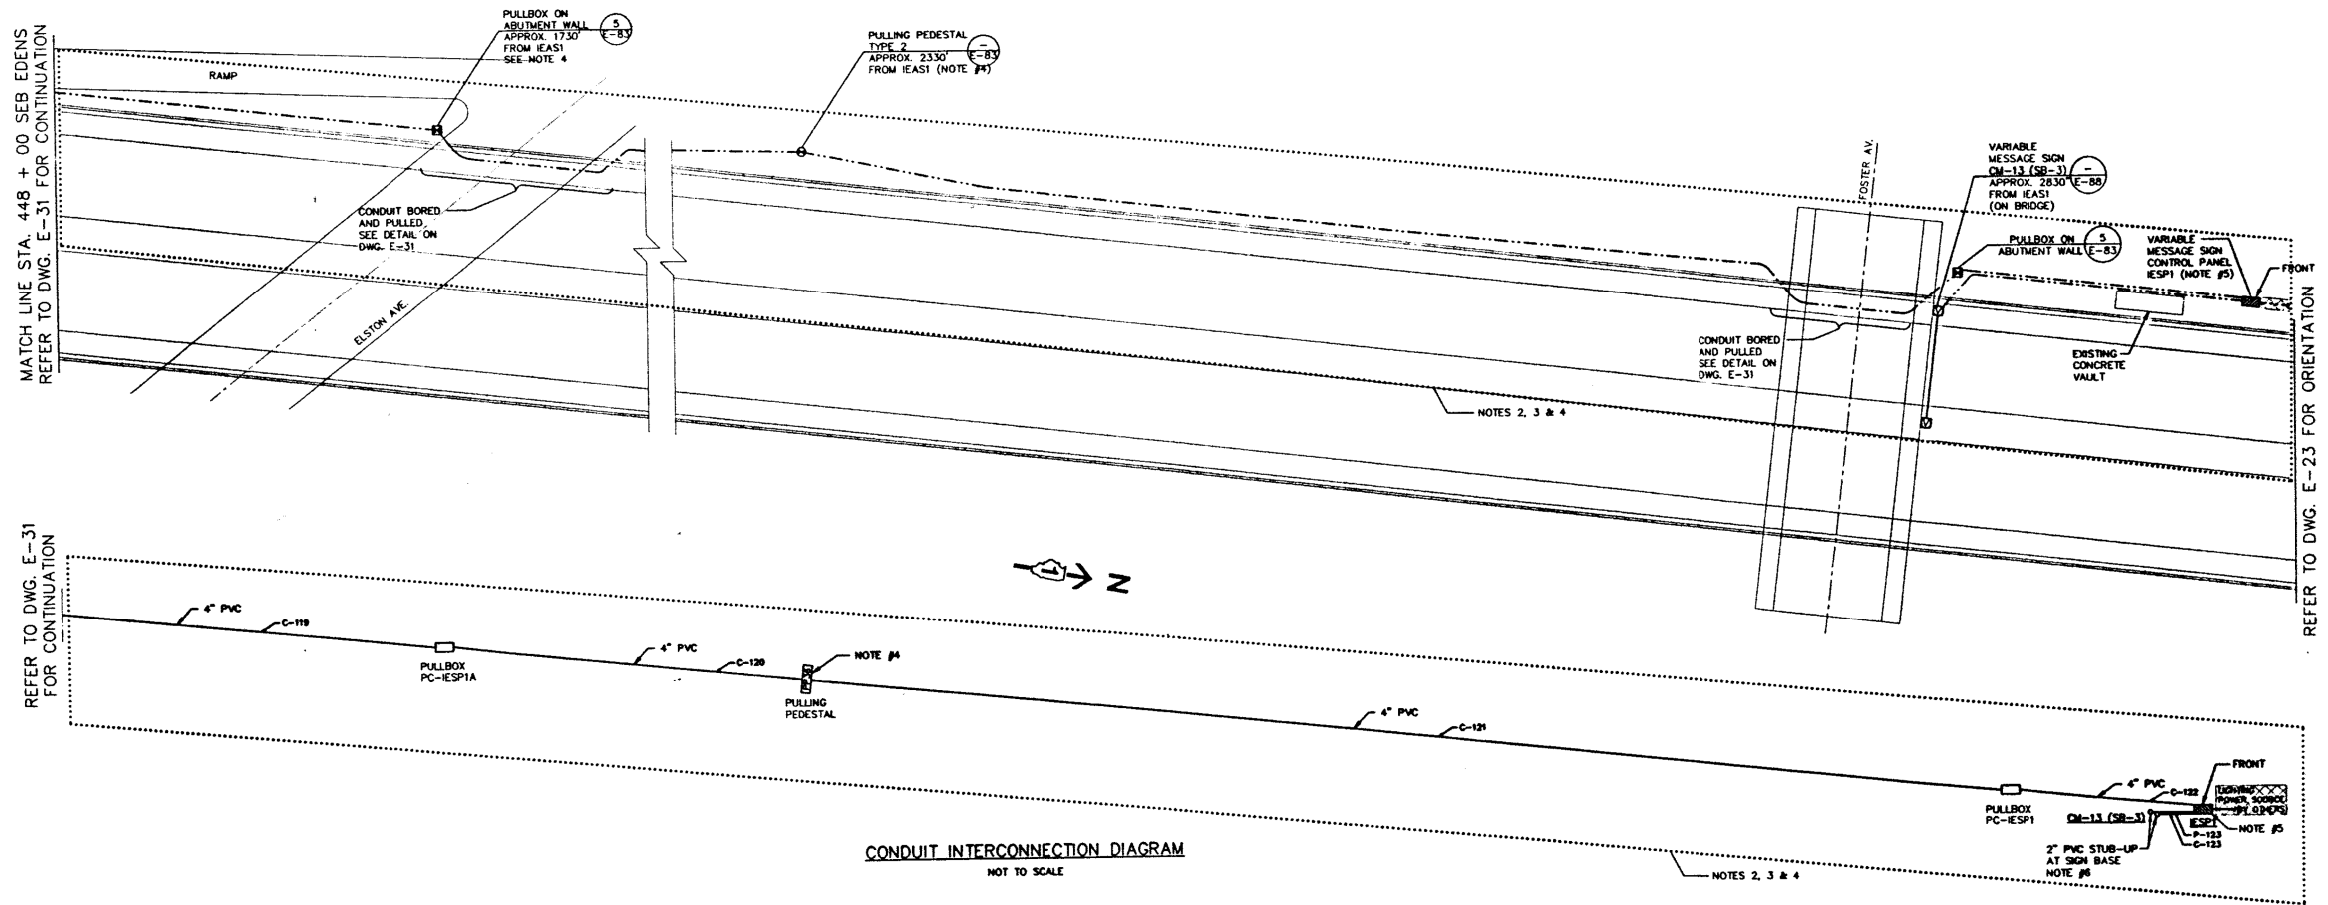

**NOTES:**

- 1.) SEE DWG. E-2 FOR GENERAL NOTES PERTAINING TO THIS DRAWING.
- 2.) UNLESS OTHERWISE INDICATED, PROVIDE ALL CABLE & WIRE FOR WORK SHOWN ON THIS SHEET, REGARDLESS OF THE CONTRACT UNDER WHICH THE ROADWAY IS PROVIDED.
- 3.) UNLESS OTHERWISE INDICATED, CONDUIT & BOXES NOT SHOWN WITHIN BOXED-OUT DASHED LINE IS EXISTING, OR WILL BE PROVIDED UNDER CONTRACT BY OTHERS.
- 4.) LOCATE PULLING PEDESTAL A MINIMUM OF 8'-0" FROM EDGE OF ROAD, OR AS DIRECTED BY THE ENGINEER.
- 5.) PROVIDE CONCRETE PAD, CONTROL PANEL CONDUITS & WIRES AS SHOWN. COORDINATE THE INSTALLATION OF THE LIGHTING CIRCUIT (BY OTHERS) INTO THE CONTROL PANEL. (SEE DWG. E-88 FOR LIGHTING CIRCUIT CONDUIT IN PAD).
- 6.) PROVIDE PVC TO H.W. RIGID CONDUIT FITTINGS & ROUTE RGS CONDUITS UP TO VARIABLE MESSAGE SIGN. SEE DWG. E-88.

**NOTES:**

1. THE ABOVE DRAWINGS REPRESENT AS LET DESIGN TO AID CONTRACTOR IN ASCERTAINING EXISTING CONDITIONS.
2. CONTRACTOR SHALL CONTACT IDOT D1 TO REQUEST THE MOST UP TO DATE RECORD DRAWINGS AVAILABLE AT THE TIME OF LETTING.

**FOR INFORMATION ONLY**

**SINGH**  
CONSULTING ENGINEERS  
www.singhinc.com


|                                        |                  |           |
|----------------------------------------|------------------|-----------|
| USER NAME = mgarvido                   | DESIGNED - DJ/AG | REVISED - |
| FILE NAME = 162.D160T93-shr-details104 | DRAWN - DS/AS    | REVISED - |
| PLOT SCALE = 2.000000:1.000000         | CHECKED - 1Y     | REVISED - |
| PLOT DATE = 06-MAY-2015 16:11          | DATE - 5/6/2015  | REVISED - |

STATE OF ILLINOIS  
DEPARTMENT OF TRANSPORTATION

INBOUND EDENS POWER & CONTROL PLAN

SCALE: NTS SHEET OF SHEETS STA. TO STA.

| F.A.I. RTE.               | SECTION   | COUNTY | TOTAL SHEETS | SHEET NO. |
|---------------------------|-----------|--------|--------------|-----------|
| 90/94                     | 2012-0521 | COOK   | 165          | 162       |
| CONTRACT NO. 60T93        |           |        |              |           |
| ILLINOIS FED. AID PROJECT |           |        |              |           |

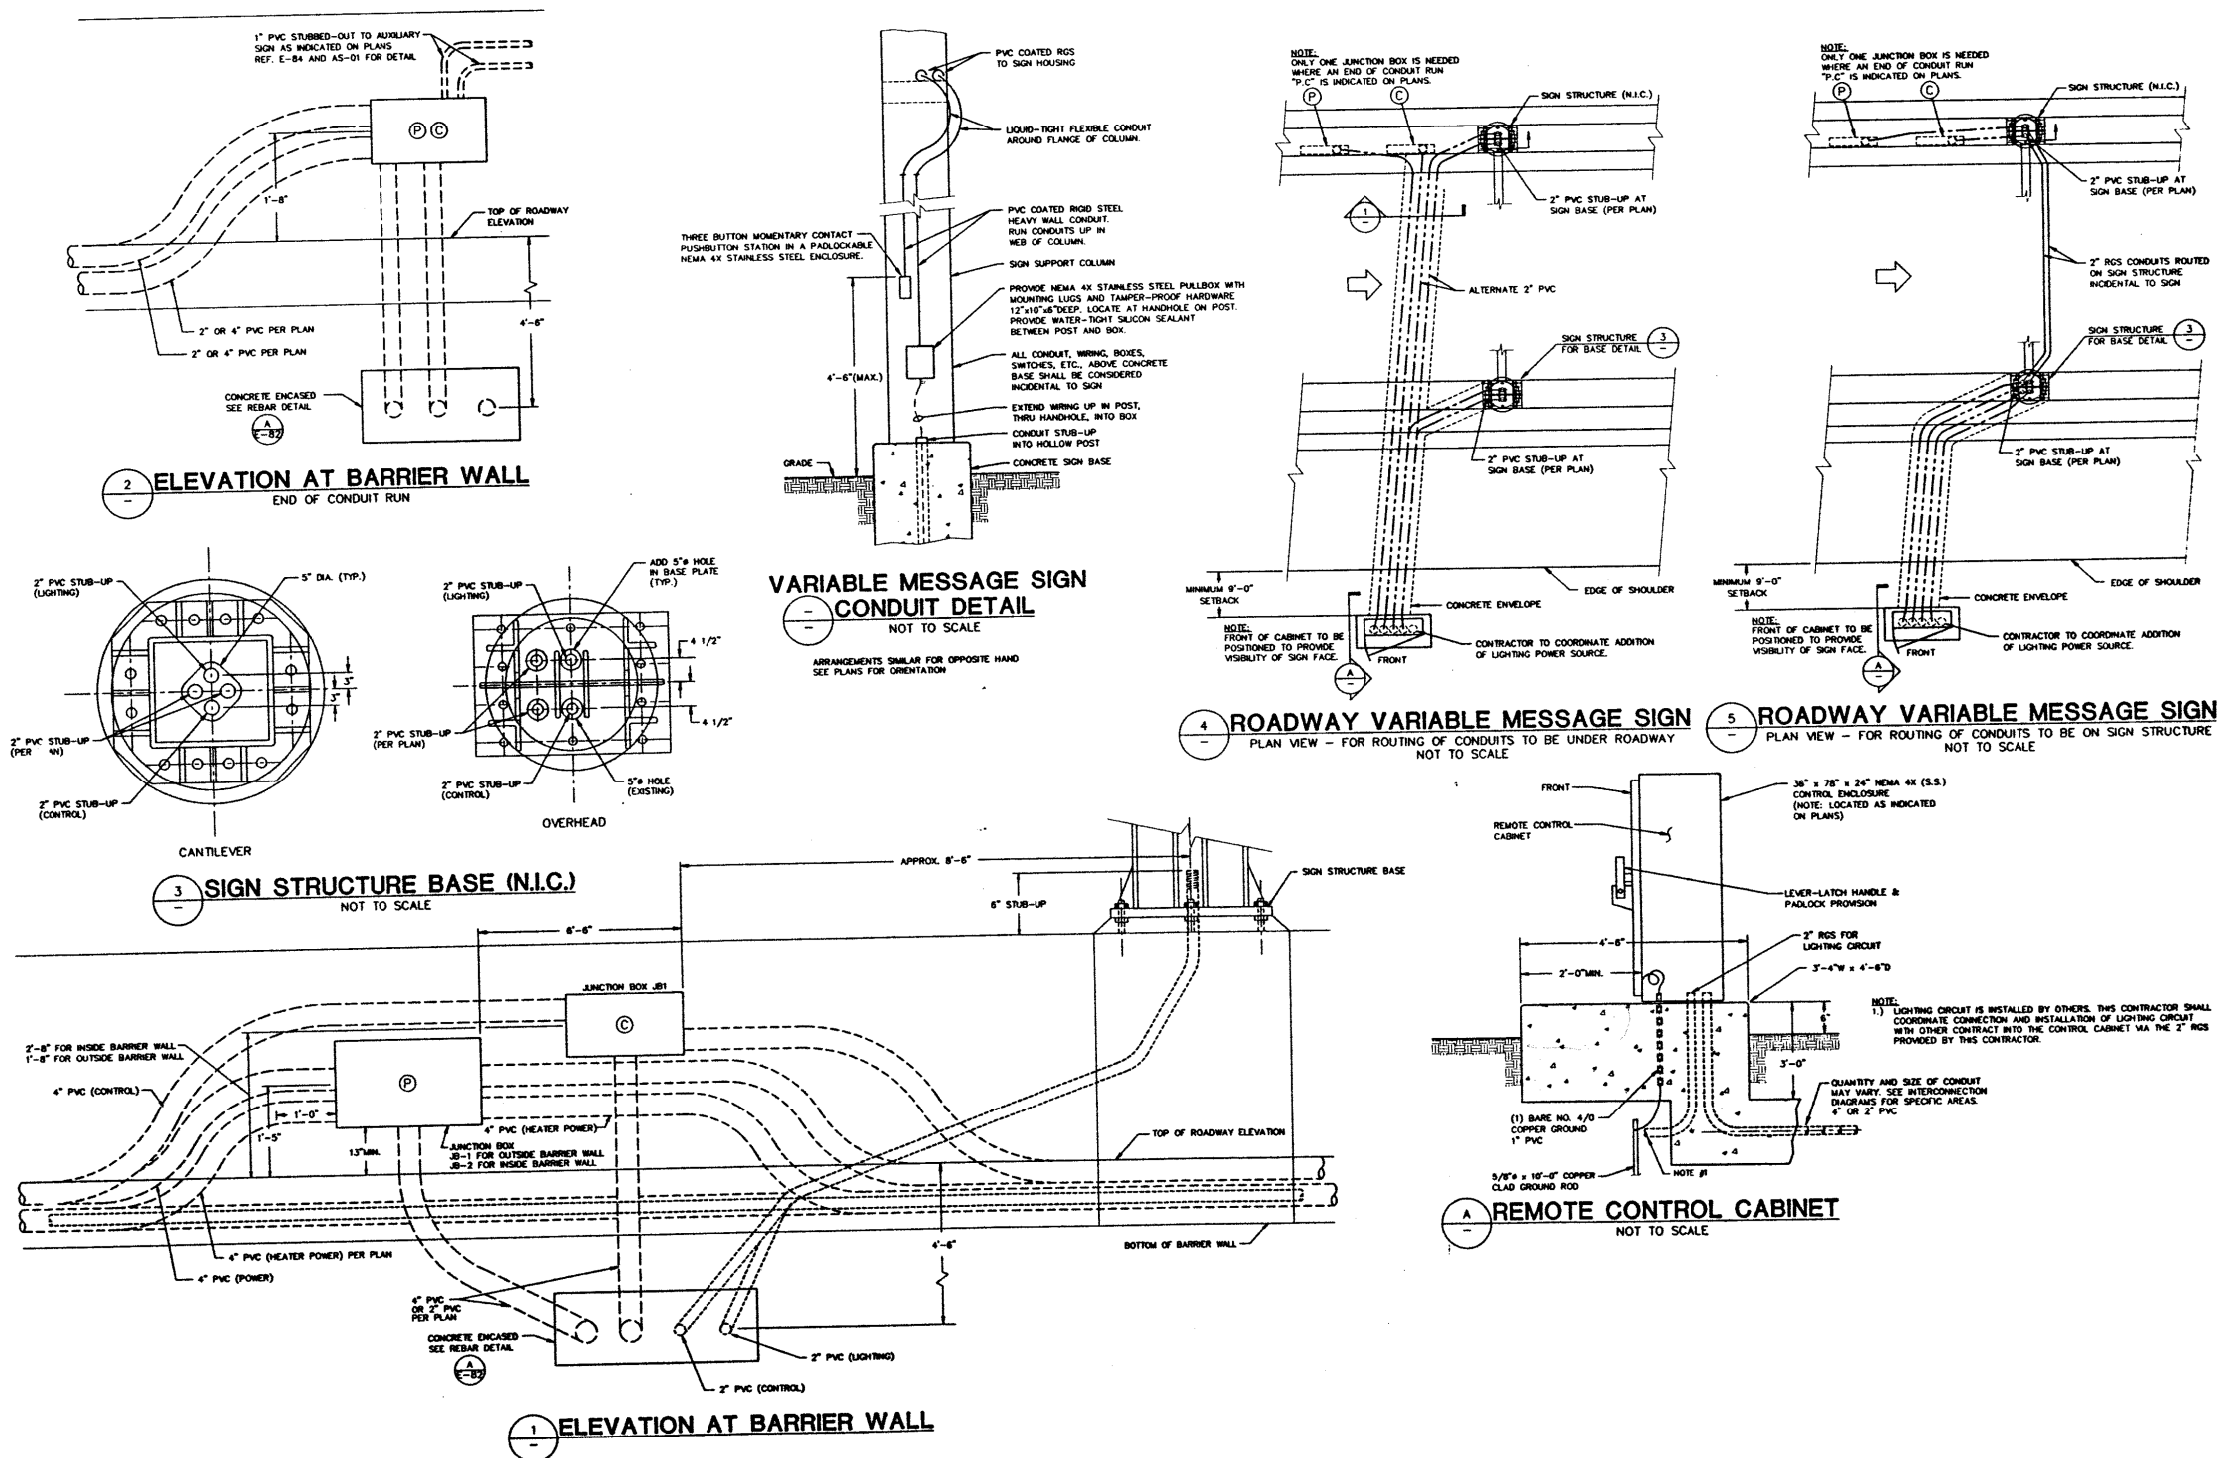

- NOTES:
1. REGULAR TEXT  
REGULAR TEXT  
REGULAR TEXT
  2. REGULAR TEXT  
REGULAR TEXT  
REGULAR TEXT

FOR INFORMATION ONLY

J:\293\Task-2\CON\CADD\_Sheet\63.Die0193-shit-details05.dgn

**SINGH**  
CONSULTING ENGINEERS  
www.singhinc.com



|                                        |                  |           |
|----------------------------------------|------------------|-----------|
| USER NAME = mgarvada                   | DESIGNED - DJ/AG | REVISED - |
| FILE NAME = 163.Die0193-shit-details05 | DRAWN - DS/AS    | REVISED - |
| PLOT SCALE = 2.000000:1.000000         | CHECKED - 1Y     | REVISED - |
| PLOT DATE = 06-MAY-2015 16:12          | DATE - 5/6/2015  | REVISED - |

STATE OF ILLINOIS  
DEPARTMENT OF TRANSPORTATION

VARIABLE MESSAGE SIGN CONDUIT DETAILS

SCALE: NTS SHEET OF SHEETS STA. TO STA.

| F.A.I. RTE.               | SECTION   | COUNTY | TOTAL SHEETS | SHEET NO. |
|---------------------------|-----------|--------|--------------|-----------|
| 90/94                     | 2012-0521 | COOK   | 165          | 163       |
| CONTRACT NO. 60T93        |           |        |              |           |
| ILLINOIS FED. AID PROJECT |           |        |              |           |

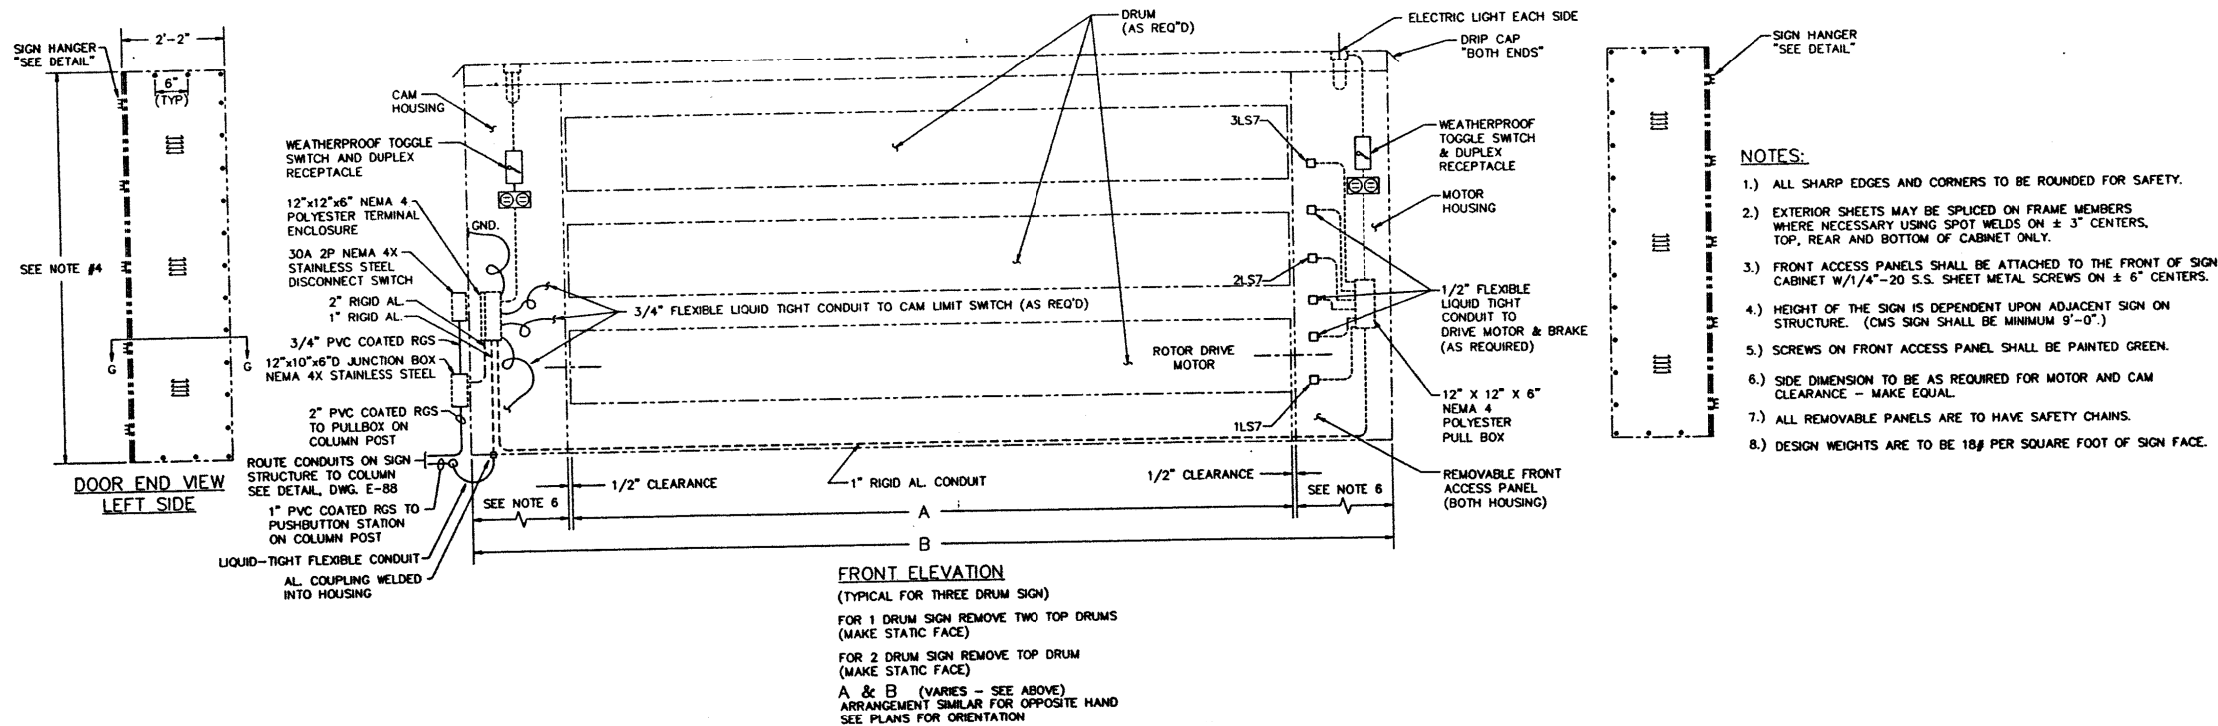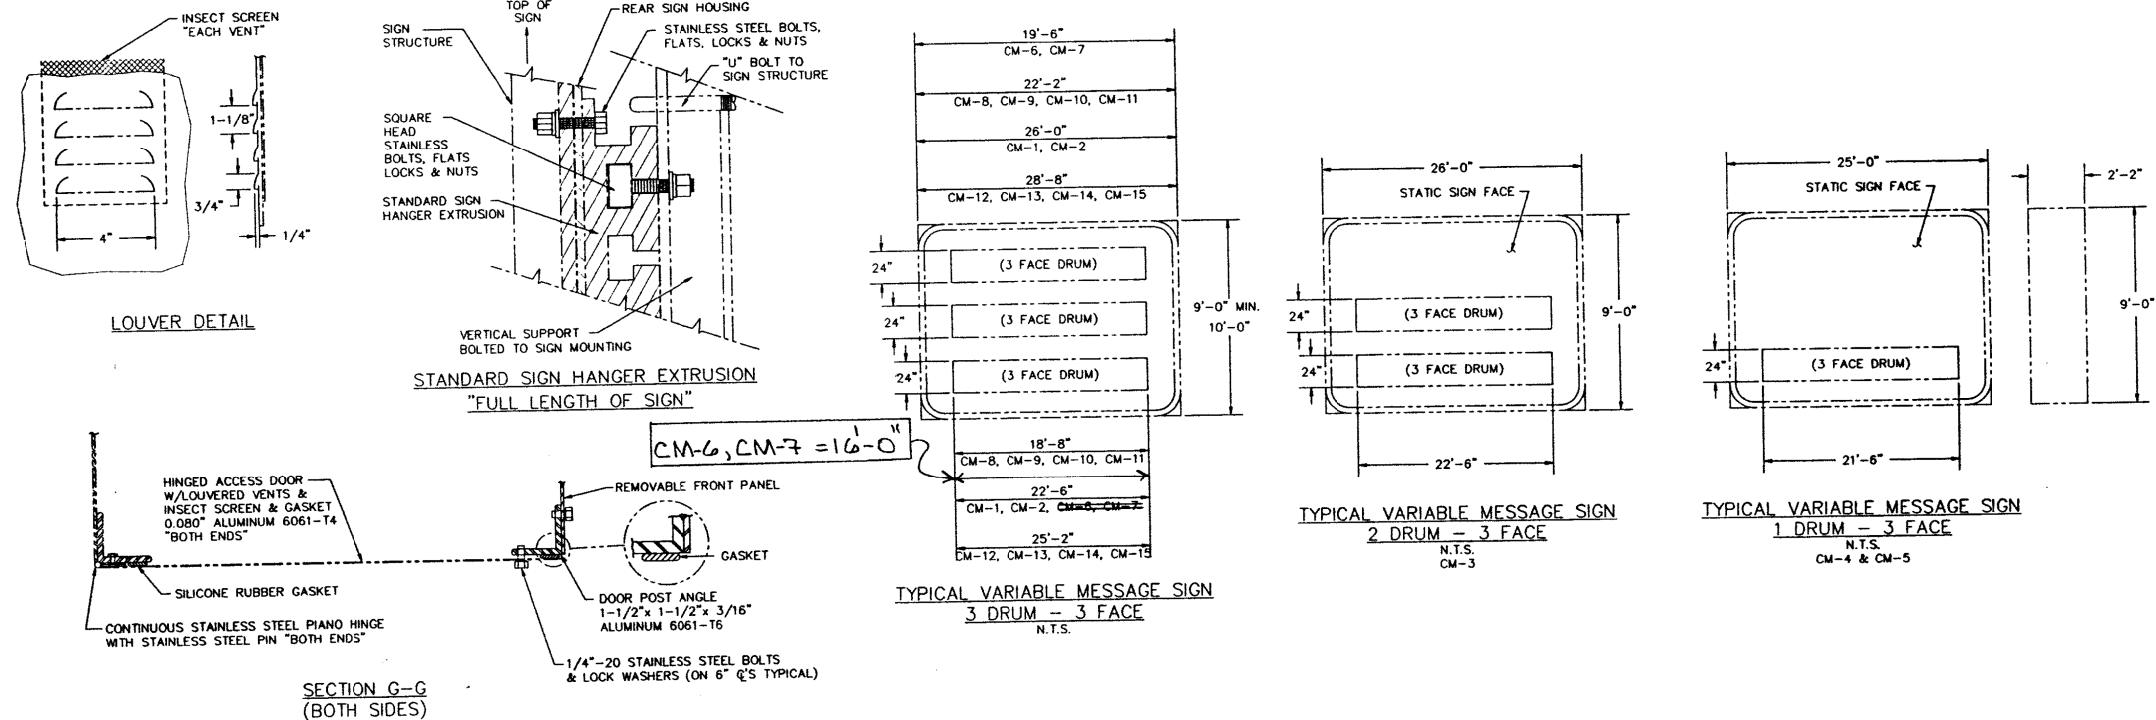

**FOR INFORMATION ONLY**

J:\293\Task-2\CON\CADD\_Sheet\64.Die0193-sh1-details06.dgn

**SINGH**  
CONSULTING ENGINEERS  
www.singhinc.com

|                                       |                  |           |
|---------------------------------------|------------------|-----------|
| USER NAME = mgarvida                  | DESIGNED - DJ/AG | REVISED - |
| FILE NAME = 164.Die0193-sh1-details06 | DRAWN - DS/AS    | REVISED - |
| PLOT SCALE = 2.000000:1.000000        | CHECKED - 1Y     | REVISED - |
| PLOT DATE = 06-MAY-2015 16:13         | DATE - 5/6/2015  | REVISED - |

**STATE OF ILLINOIS**  
**DEPARTMENT OF TRANSPORTATION**


**SIGN FACE AND SIGN CABINET DETAILS VARIABLE MESSAGE SIGN**

SCALE: NTS SHEET OF SHEETS STA. TO STA.

| F.A.I. RTE.               | SECTION   | COUNTY | TOTAL SHEETS | SHEET NO. |
|---------------------------|-----------|--------|--------------|-----------|
| 90/94                     | 2012-0521 | COOK   | 165          | 164       |
| CONTRACT NO. 60T93        |           |        |              |           |
| ILLINOIS FED. AID PROJECT |           |        |              |           |



J:\293\Task-2\CON\CADD\_Sheet\s\65\_Die0193-sh1-details07.dgn

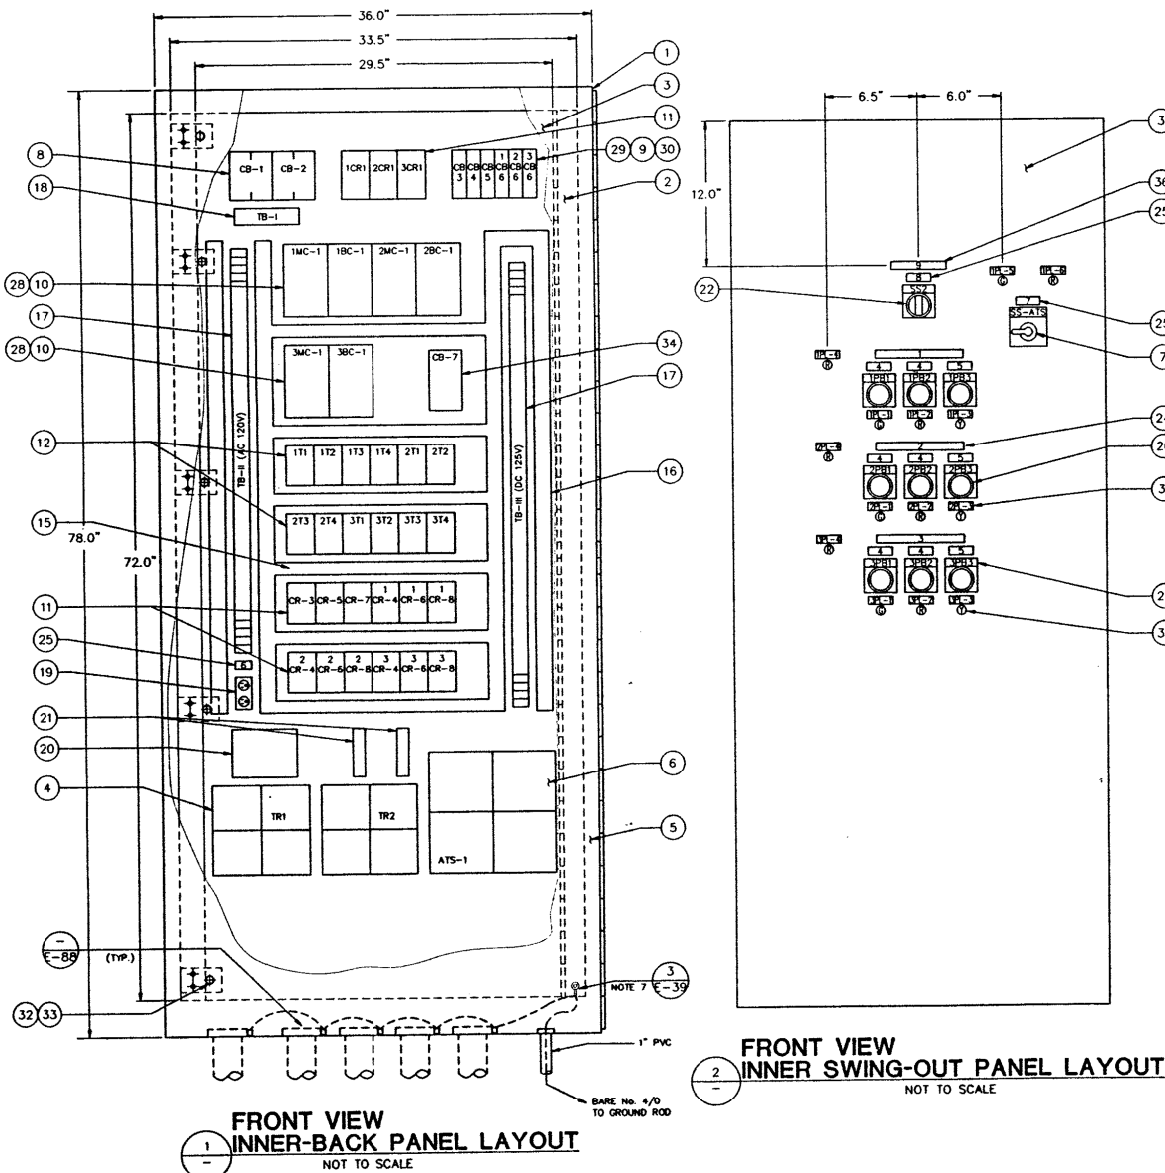

NOTES:

1. INNER SWING-OUT CONTROL PANEL WILL REQUIRE 6 CLOSING BUTTONS, REPLACING PUSHBUTTONS, NAMEPLATES & LEGEND PLATES WHEN ONLY 1 ROTOR IS USED. WHEN 2 ROTORS ARE USED, 3 CLOSING BUTTONS ARE REQUIRED.
2. PANEL AS SHOWN IS FOR 3 ROTOR LAYOUT. 2 ROTOR LAYOUT WILL BE MINUS DEVICES WITH A "2" & "3" PREFIX. 1 ROTOR LAYOUT WILL BE MINUS DEVICES WITH A "2" & "3" PREFIX.
3. RELAYS, TIMERS, CONTACTORS, TERMINAL BLOCKS & SURGE SUPPRESSOR SHOWN ARE BASED ON ALLEN BRADLEY DIMENSIONS. CIRCUIT BREAKERS & TRANSFORMERS SHOWN ARE BASED ON WESTINGHOUSE DIMENSIONS. CONTROL ENCLOSURE & INNER PANEL ARE BASED ON HOFFMAN ENGINEERING STANDARDS.
4. QUANTITY OF LED INDICATING LIGHTS & NAMEPLATES SHALL CORRESPOND WITH NUMBER OF ROTORS USED. (SEE NOTE 2)
5. LAMINATED PHENOLIC NAMEPLATES SHALL HAVE WHITE LETTERS ON BLACK BACKGROUND. (SIZED TO LENGTH OF NAMEPLATE)
6. DIMENSIONS & DETAILS SHOWN ARE FOR PLANNING PURPOSES ONLY. THE CONTRACTOR IS RESPONSIBLE FOR LAYOUTS & WIRING REQUIREMENTS.
7. PROVIDE A PANEL GROUNDING AS E-39, DETAIL 3.

TABLE A

| NP | ENGRAVE                             | QTY.   |
|----|-------------------------------------|--------|
| 1  | TOP LINE                            | 1      |
| 2  | MIDDLE LINE                         | NOTE 4 |
| 3  | BOTTOM LINE                         | NOTE 4 |
| 4  | EXPRESS                             | NOTE 4 |
| 5  | BLANK                               | NOTE 4 |
| 6  | 120V AC                             | 1      |
| 7  | ATS CONTROL SWITCH                  | 1      |
| 8  | CONTROL MODE SELECTOR SWITCH        | 1      |
| 9  | VARIABLE MESSAGE SIGN CONTROL PANEL | 1      |
| 10 |                                     |        |

TABLE B

| DEVICE | ENGRAVE                   |
|--------|---------------------------|
| SS2    | REMOTE - OFF - LOCAL      |
| SS-ATS | NORMAL EMERGENCY          |
| 1PB1   | LANE OPEN STATE           |
| 2PB1   | LANE OPEN STATE           |
| 3PB1   | LANE OPEN STATE           |
| 1PB2   | LANE CLOSE STATE          |
| 2PB2   | LANE CLOSE STATE          |
| 3PB2   | LANE CLOSE STATE          |
| 1PB3   | BLANK STATE               |
| 2PB3   | BLANK STATE               |
| 3PB3   | BLANK STATE               |
| 1PL-1  | LANE OPEN STATE           |
| 2PL-1  | LANE OPEN STATE           |
| 3PL-1  | LANE OPEN STATE           |
| 1PL-2  | LANE CLOSE STATE          |
| 2PL-2  | LANE CLOSE STATE          |
| 3PL-2  | LANE CLOSE STATE          |
| 1PL-3  | BLANK STATE               |
| 2PL-3  | BLANK STATE               |
| 3PL-3  | BLANK STATE               |
| 1PL-4  | MOTOR O/L                 |
| 2PL-4  | MOTOR O/L                 |
| 3PL-4  | MOTOR O/L                 |
| 1PL-5  | NORMAL REV/LAC SUPPLY     |
| 1PL-6  | EMERGENCY LIGHTING SUPPLY |

| ITEM | QTY.     | DESCRIPTION                                                                                          | REMARKS     |
|------|----------|------------------------------------------------------------------------------------------------------|-------------|
| 1    | 1        | CTRL ENCL 36.0"x78.0"x24.0" DIA. ST.SL. SINGLE DOOR HINGED RIGHT SIDE, 3-POINT LATCH, PADLOCK HANDLE |             |
| 2    | 1        | INNER BACK PANEL 33.5" x 72.0"                                                                       |             |
| 3    | 1        | INNER SWING-OUT PANEL 29.5" x 72.0", 10GA HINGED RIGHT SIDE WITH QUARTER TURN LATCHES                |             |
| 4    | 2        | CONTROL TRANSFORMER 3 KVA, 480/120V 1Ø                                                               |             |
| 5    | 1        | DOOR PANEL (HINGED RIGHT SIDE)                                                                       |             |
| 6    | 1        | AUTOMATIC TRANSFER SWITCH 30A-2P                                                                     |             |
| 7    | 1        | AUTOMATIC TRANSFER SWITCH CONTROL TOGGLE SWITCH                                                      |             |
| 8    | 2        | CIRCUIT BREAKER 10A-2P, 480VAC                                                                       |             |
| 9    | *        | CIRCUIT BREAKER 15A-1P, 120VAC                                                                       | NOTE 2      |
| 10   | *        | CONTACTOR, SIZE 1, 120V OPEN TYPE                                                                    | NOTE 2      |
| 11   | *        | CONTROL RELAY, 4P (CONV. CONT.) OPEN TYPE                                                            | NOTE 2      |
| 12   | *        | CONTROL RELAY, 4P (CONV. CONT.) OPEN TYPE W/SOLID-STATE TIMER (5 SEC.)                               | NOTE 2      |
| 13   | -        | -                                                                                                    |             |
| 14   | -        | -                                                                                                    |             |
| 15   | AS REQ'D | WIRE DUCT 1.0" x 3.0" HIGH W/COVER                                                                   |             |
| 16   | AS REQ'D | WIRE DUCT 2.0" x 3.0" HIGH W/COVER                                                                   |             |
| 17   | AS REQ'D | TERMINAL BLOCK ASSEMBLY 300V                                                                         |             |
| 18   | 12       | TERMINAL BLOCK ASSEMBLY 600V W/COVER                                                                 |             |
| 19   | 1        | RECEPTACLE, DUPLEX W/ENCL.                                                                           |             |
| 20   | 1        | POWER LINE FILTER 30A 120VAC 60Hz                                                                    |             |
| 21   | 2        | SURGE SUPPRESSOR, SIZE 1, 120V                                                                       |             |
| 22   | 1        | SELECTOR SWITCH, 3 POSITION, 7 N.C., 1 N.O. CONTACTS ROTARY TYPE, STANDARD KNOB (4 POLES)            |             |
| 23   | *        | LEGEND PLATES (LARGE) ENGRAVE PER TABLE B                                                            | NOTES 1 & 2 |
| 24   | 3        | NAMEPLATES, LAMINATED PHENOLIC 0.5" x 7.5" ENGRAVE PER TABLE A                                       | NOTES 1 & 2 |
| 25   | 11       | NAMEPLATES, LAMINATED PHENOLIC 0.5" x 2.5" ENGRAVE PER TABLE A                                       |             |
| 26   | *        | PUSHBUTTON, 1 N.C., 1 N.O. CONTACTS GREEN COLOR CAP                                                  | NOTE 1 & 2  |
| 27   | *        | CLOSING BUTTONS                                                                                      | NOTE 1      |
| 28   | 12'      | RELAY MOUNTING RAIL                                                                                  |             |
| 29   | 2        | CIRCUIT BREAKER 30A-1P, 120VAC                                                                       |             |
| 30   | 1        | CIRCUIT BREAKER 20A-1P, 120VAC                                                                       |             |
| 31   | AS REQ'D | NAMEPLATES, LAMINATED PHENOLIC 0.5" x 2.5" ENGRAVE PER TABLE B                                       |             |
| 32   | 2        | INNER SWING-OUT PANEL BRACKETS                                                                       |             |
| 33   | 2        | 1/4 TURN FASTENERS (DZUS OR EQUAL)                                                                   |             |
| 34   | 1        | GFI CIRCUIT BREAKER                                                                                  |             |
| 35   | AS REQ'D | INDICATING LIGHTS (125VDC) LED .375"DIA. 7 RED, 3 YELLOW, 4 GREEN                                    | NOTE 4      |
| 36   | 1        | NAMEPLATES, LAMINATED PHENOLIC 2.5" x 4.5" ENGRAVE PER TABLE A                                       |             |

\* SEE NOTES 1 & 2 TO DETERMINE QUANTITY  
\*\* DENOTES PANEL NOMENCLATURE

FOR INFORMATION ONLY