



MODEL: Default
FILE NAME: \\001\projects\2121304_CADD_01\CADD_Sheets\Woodfield-Sht-16_National Pkwy_Prop Cable Plan.dgn

PROPOSED CONTROLLER SEQUENCE

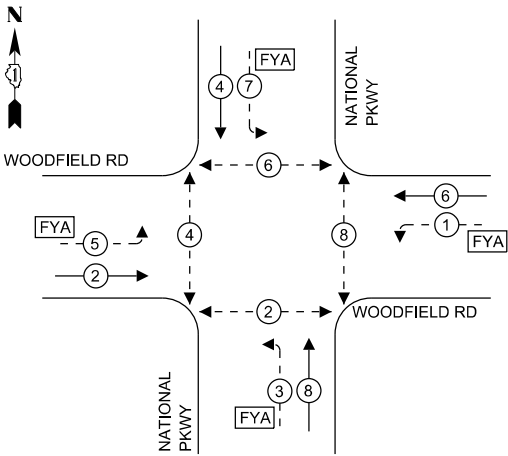

PROPOSED EMERGENCY VEHICLE
PREEMPTION SEQUENCE

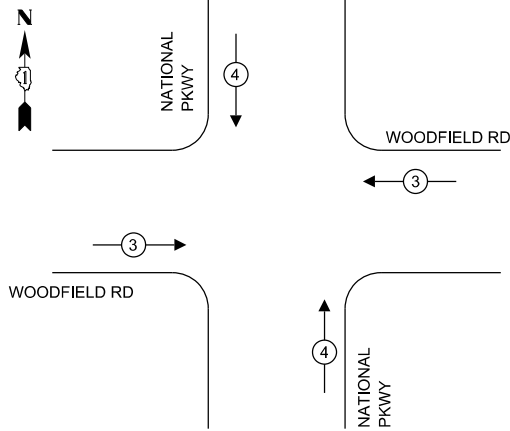

LEGEND:

- ← (⊙) ← PROTECTED PHASE
- ← (⊙) - - PROTECTED/PERMITTED PHASE
- ← (⊙) → PEDESTRIAN PHASE
- ← (⊙) OL OVERLAP
- [FYA] FLASHING YELLOW ARROW

TRAFFIC SIGNAL
ELECTRICAL SERVICE REQUIREMENTS

EQUIPMENT TYPE	QUANTITY	UNIT WATTAGE	TOTAL WATTAGE
SIGNAL HEAD 1 OR 3-SECTION	12	11	132
4-SECTION	-	14	-
5-SECTION	8	13	104
PROGRAMMABLE 3-SECTION	-	22	-
4-SECTION	-	32	-
5-SECTION	-	28	-
PEDESTRIAN SIGNAL	8	15	120
CONTROLLER	1	150	150
MASTER CONTROLLER	-	100	-
UPS	1	25	25
DETECTION RADAR OR VIDEO	1	20	20
BLANK-OUT SIGN	-	25	-
NETWORK SWITCH II OR III	-	35	-
CELLULAR MODEM	-	15	-
TOTAL UPS SIZING			551
UPS CHARGING	1	225	225
BATTERY HEATER MAT	1	180	180
CABINET HEATER	1	200	200
FLASHER	-	15	-
LED STREET NAME SIGN	-	120	-
LUMINAIRE	-	240	-
TOTAL SERVICE WIRE SIZING			1,156

NOTES

- ALL RED SIGNAL INDICATIONS SHALL HAVE A LENS COVER

ENERGY COSTS TO:

VILLAGE OF SCHAUMBURG

101 SCHAUMBURG COURT
SCHAUMBURG, IL 60193

ENERGY SUPPLY: CONTACT: ARTURO SALDIVAR

PHONE:

COMPANY: COMED

ACCOUNT NUMBER: XXXXX-XXXXX

TOWER ACCOUNT NUMBER: 0245068017

SINGH
SINGH & ASSOCIATES INC.
CONSULTING ENGINEERS


USER NAME = jturk
PLOT SCALE = 2,0000 ' / in.
PLOT DATE = 9/8/2025

DESIGNED - EEC
DRAWN - EEC
CHECKED - MG
DATE - 09/05/2025

REVISED -
REVISED -
REVISED -
REVISED -

STATE OF ILLINOIS
DEPARTMENT OF TRANSPORTATION

CABLE PLAN
(NOT TO SCALE)

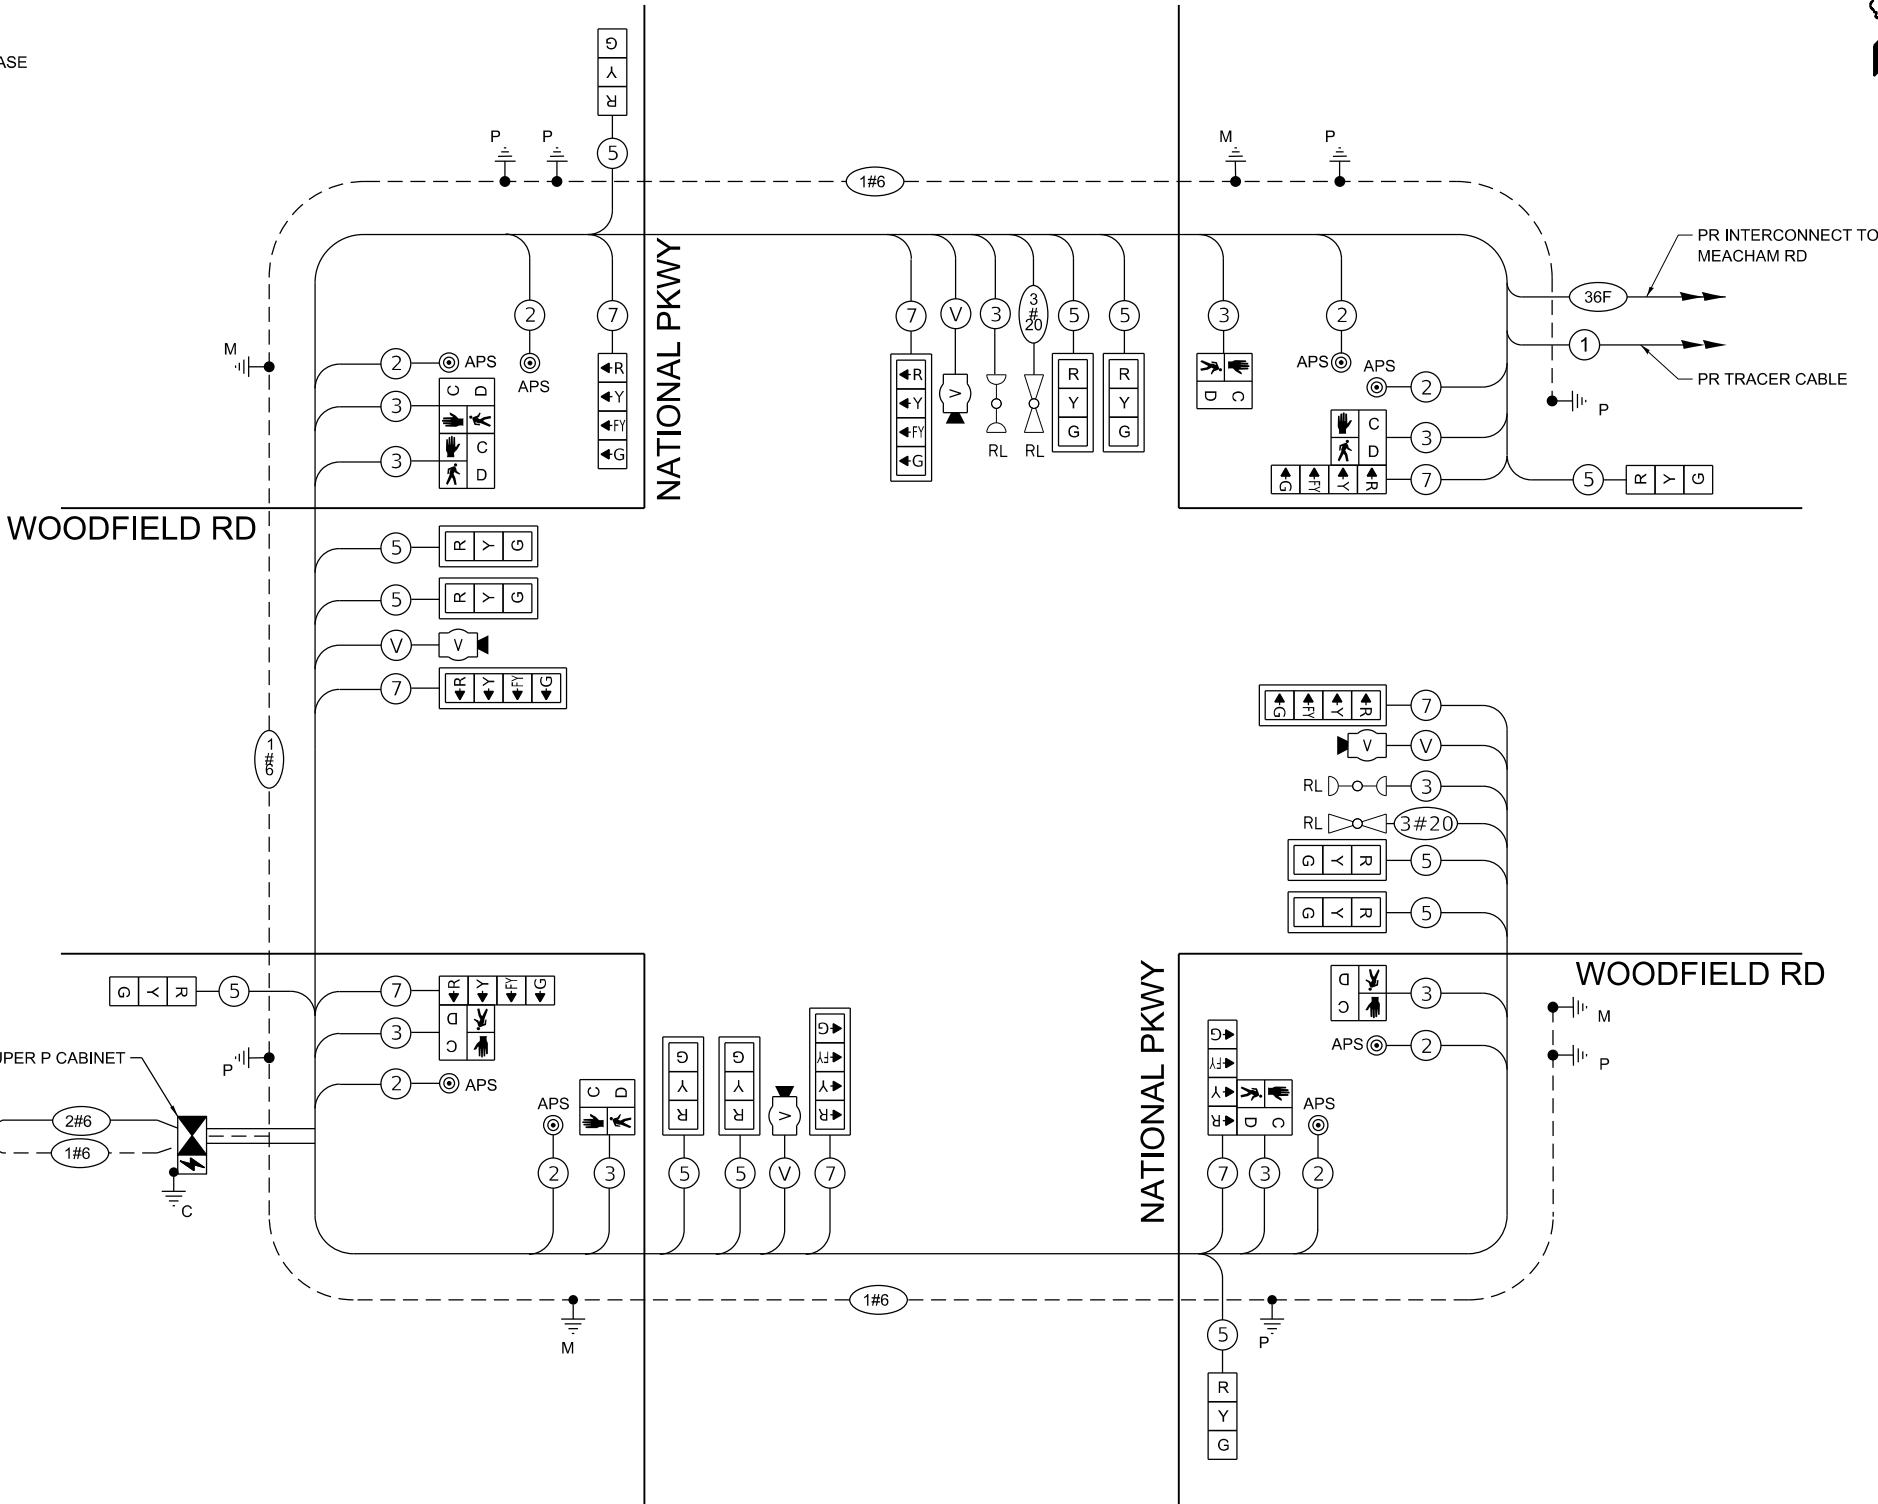


CABLE PLAN, PHASE DESIGNATION DIAGRAM, AND
EMERGENCY VEHICLE PREEMPTION SEQUENCE
WOODFIELD ROAD AT NATIONAL PARKWAY


SCALE: NTS SHEET 1 OF 1 SHEETS STA. TO STA.

F.A.U. RTE.	SECTION	COUNTY	TOTAL SHEETS	SHEET NO.
3073	20-00134-00-R5	COOK	166	101
CONTRACT NO. 61L43				
ILLINOIS FED. AID PROJECT				


SIGN PANEL – TYPE 1 OR TYPE 2
ALL DIMENSIONS ARE IN INCHES UNLESS NOTED OTHERWISE

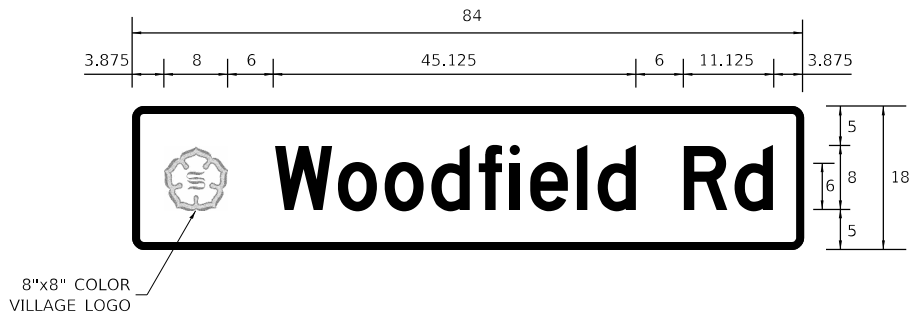


DESIGN SERIES	AREA (SQ FT)	QTY. REQUIRED
D	10.5	2

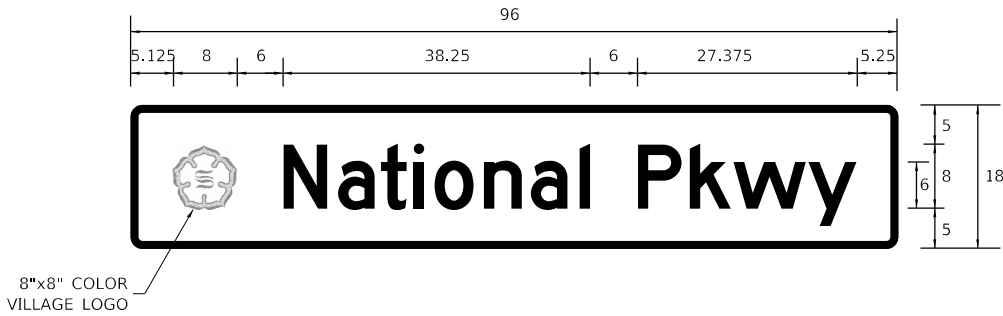

DESIGN SERIES	AREA (SQ FT)	QTY. REQUIRED
D	12	2

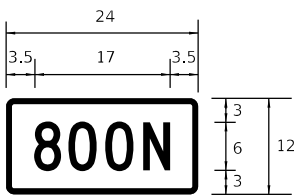

DESIGN SERIES	AREA (SQ FT)	QTY. REQUIRED
C	2	2

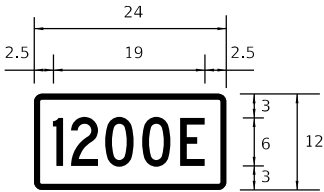

DESIGN SERIES	AREA (SQ FT)	QTY. REQUIRED
C	2	2

NOTE: FOR ADDITIONAL DESIGN AND INSTALLATION INFORMATION PLEASE SEE DISTRICT ONE MAST ARM MOUNTED STREET NAME SIGNS DETAIL.

SCHEDULE OF QUANTITIES

ITEM DESCRIPTION	UNITS	TOTAL QTY
SIGN PANEL - TYPE 1	SQ FT	68
SIGN PANEL - TYPE 2	SQ FT	45
UNDERGROUND CONDUIT, GALVANIZED STEEL, 2" DIA.	FOOT	106
UNDERGROUND CONDUIT, GALVANIZED STEEL, 3" DIA.	FOOT	192
UNDERGROUND CONDUIT, GALVANIZED STEEL, 4" DIA.	FOOT	406
HANDHOLE	EACH	2
DOUBLE HANDHOLE	EACH	2
* PAINT NEW TRAFFIC SIGNAL POST	EACH	4
* PAINT NEW MAST ARM AND POLE, 40 FOOT AND OVER	EACH	4
ELECTRIC CABLE IN CONDUIT, SIGNAL NO. 14 2C	FOOT	1,421
ELECTRIC CABLE IN CONDUIT, SIGNAL NO. 14 3C	FOOT	1,838
ELECTRIC CABLE IN CONDUIT, SIGNAL NO. 14 5C	FOOT	2,238
ELECTRIC CABLE IN CONDUIT, SIGNAL NO. 14 7C	FOOT	1,518
ELECTRIC CABLE IN CONDUIT, SERVICE, NO. 6 2 C	FOOT	48
ELECTRIC CABLE IN CONDUIT, EQUIPMENT GROUNDING CONDUCTOR, NO. 6 1C	FOOT	1,493
TRAFFIC SIGNAL POST, 16 FT.	EACH	4
STEEL MAST ARM ASSEMBLY AND POLE, 40 FT.	EACH	3
STEEL MAST ARM ASSEMBLY AND POLE, 42 FT.	EACH	1
CONCRETE FOUNDATION, TYPE A	FOOT	16
CONCRETE FOUNDATION, TYPE C	FOOT	4
CONCRETE FOUNDATION, TYPE E 36-INCH DIAMETER	FOOT	52
SIGNAL HEAD, LED, 1-FACE, 3-SECTION, MAST-ARM MOUNTED	EACH	8
SIGNAL HEAD, LED, 1-FACE, 3-SECTION, BRACKET MOUNTED	EACH	4
SIGNAL HEAD, LED, 1-FACE, 4-SECTION, BRACKET MOUNTED	EACH	4
SIGNAL HEAD, LED, 1-FACE, 4-SECTION, MAST-ARM MOUNTED	EACH	4
PEDESTRIAN SIGNAL HEAD, LED, 1-FACE, BRACKET MOUNTED WITH COUNTDOWN TIMER	EACH	8
TRAFFIC SIGNAL BACKPLATE, LOUVERED, FORMED PLASTIC	EACH	12
TEMPORARY TRAFFIC SIGNAL INSTALLATION	EACH	1
* RELOCATE EXISTING EMERGENCY VEHICLE PRIORITY SYSTEM, DETECTOR UNIT	EACH	2
* RELOCATE EXISTING EMERGENCY VEHICLE PRIORITY SYSTEM, PHASING UNIT	EACH	1
REMOVE ELECTRIC CABLE FROM CONDUIT	FOOT	4,900
REMOVE EXISTING TRAFFIC SIGNAL EQUIPMENT	EACH	1
REMOVE EXISTING HANDHOLE	EACH	8
REMOVE EXISTING DOUBLE HANDHOLE	EACH	2
REMOVE EXISTING CONCRETE FOUNDATION	EACH	9
* EMERGENCY VEHICLE PRIORITY SYSTEM LINE SENSOR CABLE, NO. 20 3/C	FOOT	531
SERVICE INSTALLATION, GROUND MOUNTED, METERED	EACH	1
PEDESTRIAN SIGNAL POST, 10 FT.	EACH	1
PEDESTRIAN SIGNAL POST, 5 FT.	EACH	2
* PAINT NEW PEDESTRIAN PUSH-BUTTON POST	EACH	3
FULL-ACTUATED CONTROLLER AND TYPE SUPER P CABINET (SPECIAL)	EACH	1
UNINTERRUPTABLE POWER SUPPLY, SPECIAL	EACH	1
ACCESSIBLE PEDESTRIAN SIGNALS	EACH	8
CONCRETE FOUNDATION, TYPE A 12-INCH DIAMETER	FOOT	12
LED SIGNAL FACE, LENS COVER	EACH	20
VIDEO VEHICLE DETECTION SYSTEM	EACH	1
TEMPORARY TRAFFIC SIGNAL TIMING	EACH	1

* 100% COST TO THE VILLAGE OF SCHAUMBURG

MODEL: Default
FILE NAME: W0119project2121304_CADD_01\CADD_Sheets\Woodfield-Sht-18_Meacham Rd Temp Signal Plan.dgn



USER NAME	= ggedemer	DESIGNED -	EEC	REVISED -	
		DRAWN -	EEC	REVISED -	
PLOT SCALE	= 40,0000 ' / in.	CHECKED -	MG	REVISED -	
PLOT DATE	= 9/5/2025	DATE	= 09/05/2025	REVISED -	

STATE OF ILLINOIS
DEPARTMENT OF TRANSPORTATION

TEMPORARY TRAFFIC SIGNAL INSTALLATION AND REMOVAL PLAN
WOODFIELD ROAD AT MEACHAM ROAD

SCALE: 1"=20' SHEET 1 OF 2 SHEETS STA. TO STA.

F.A.U. RTE.	SECTION	COUNTY	TOTAL SHEETS	SHEET NO.
3073	20-00134-00-R5	COOK	166	103
CONTRACT NO. 61L43				
ILLINOIS FED. AID PROJECT				



REMOVAL AND RELOCATION NOTES

THE FOLLOWING ITEMS SHALL BE REMOVED BY THE CONTRACTOR AND SHALL BE DISPOSED OF BY THEM OUTSIDE THE RIGHT-OF-WAY AT THEIR EXPENSE. THE SALVAGE VALUE OF THE REMOVED EQUIPMENT SHALL BE REFLECTED IN THE CONTRACT BID PRICE.

1	EACH	CONTROLLER AND CABINET (COMPLETE)
4	EACH	STEEL MAST ARM ASSEMBLY AND POST
4	EACH	TRAFFIC SIGNAL POST
16	EACH	3-SECTION SIGNAL HEAD
4	EACH	5-SECTION SIGNAL HEAD
16	EACH	PEDESTRIAN SIGNAL HEAD
8	EACH	PEDESTRIAN PUSH BUTTON
1	EACH	SERVICE INSTALLATION
12	EACH	TRAFFIC SIGNAL BACKPLATE
4	EACH	VIDEO DETECTION CAMERA

THE FOLLOWING ITEMS SHALL BE REMOVED FROM THE EXISTING TRAFFIC SIGNAL INSTALLATION BY THE CONTRACTOR, SAFELY STORED, AND RELOCATED TO THE PROPOSED TRAFFIC SIGNAL INSTALLATION. ANY EQUIPMENT THAT IS DAMAGED BY THE CONTRACTOR SHALL BE REPLACED WITH NEW EQUIPMENT AT NO ADDITIONAL COST TO THE CONTRACT.

2	EACH	CONFIRMATION BEACON
2	EACH	LIGHT DETECTOR
1	EACH	LIGHT DETECTOR AMPLIFIER

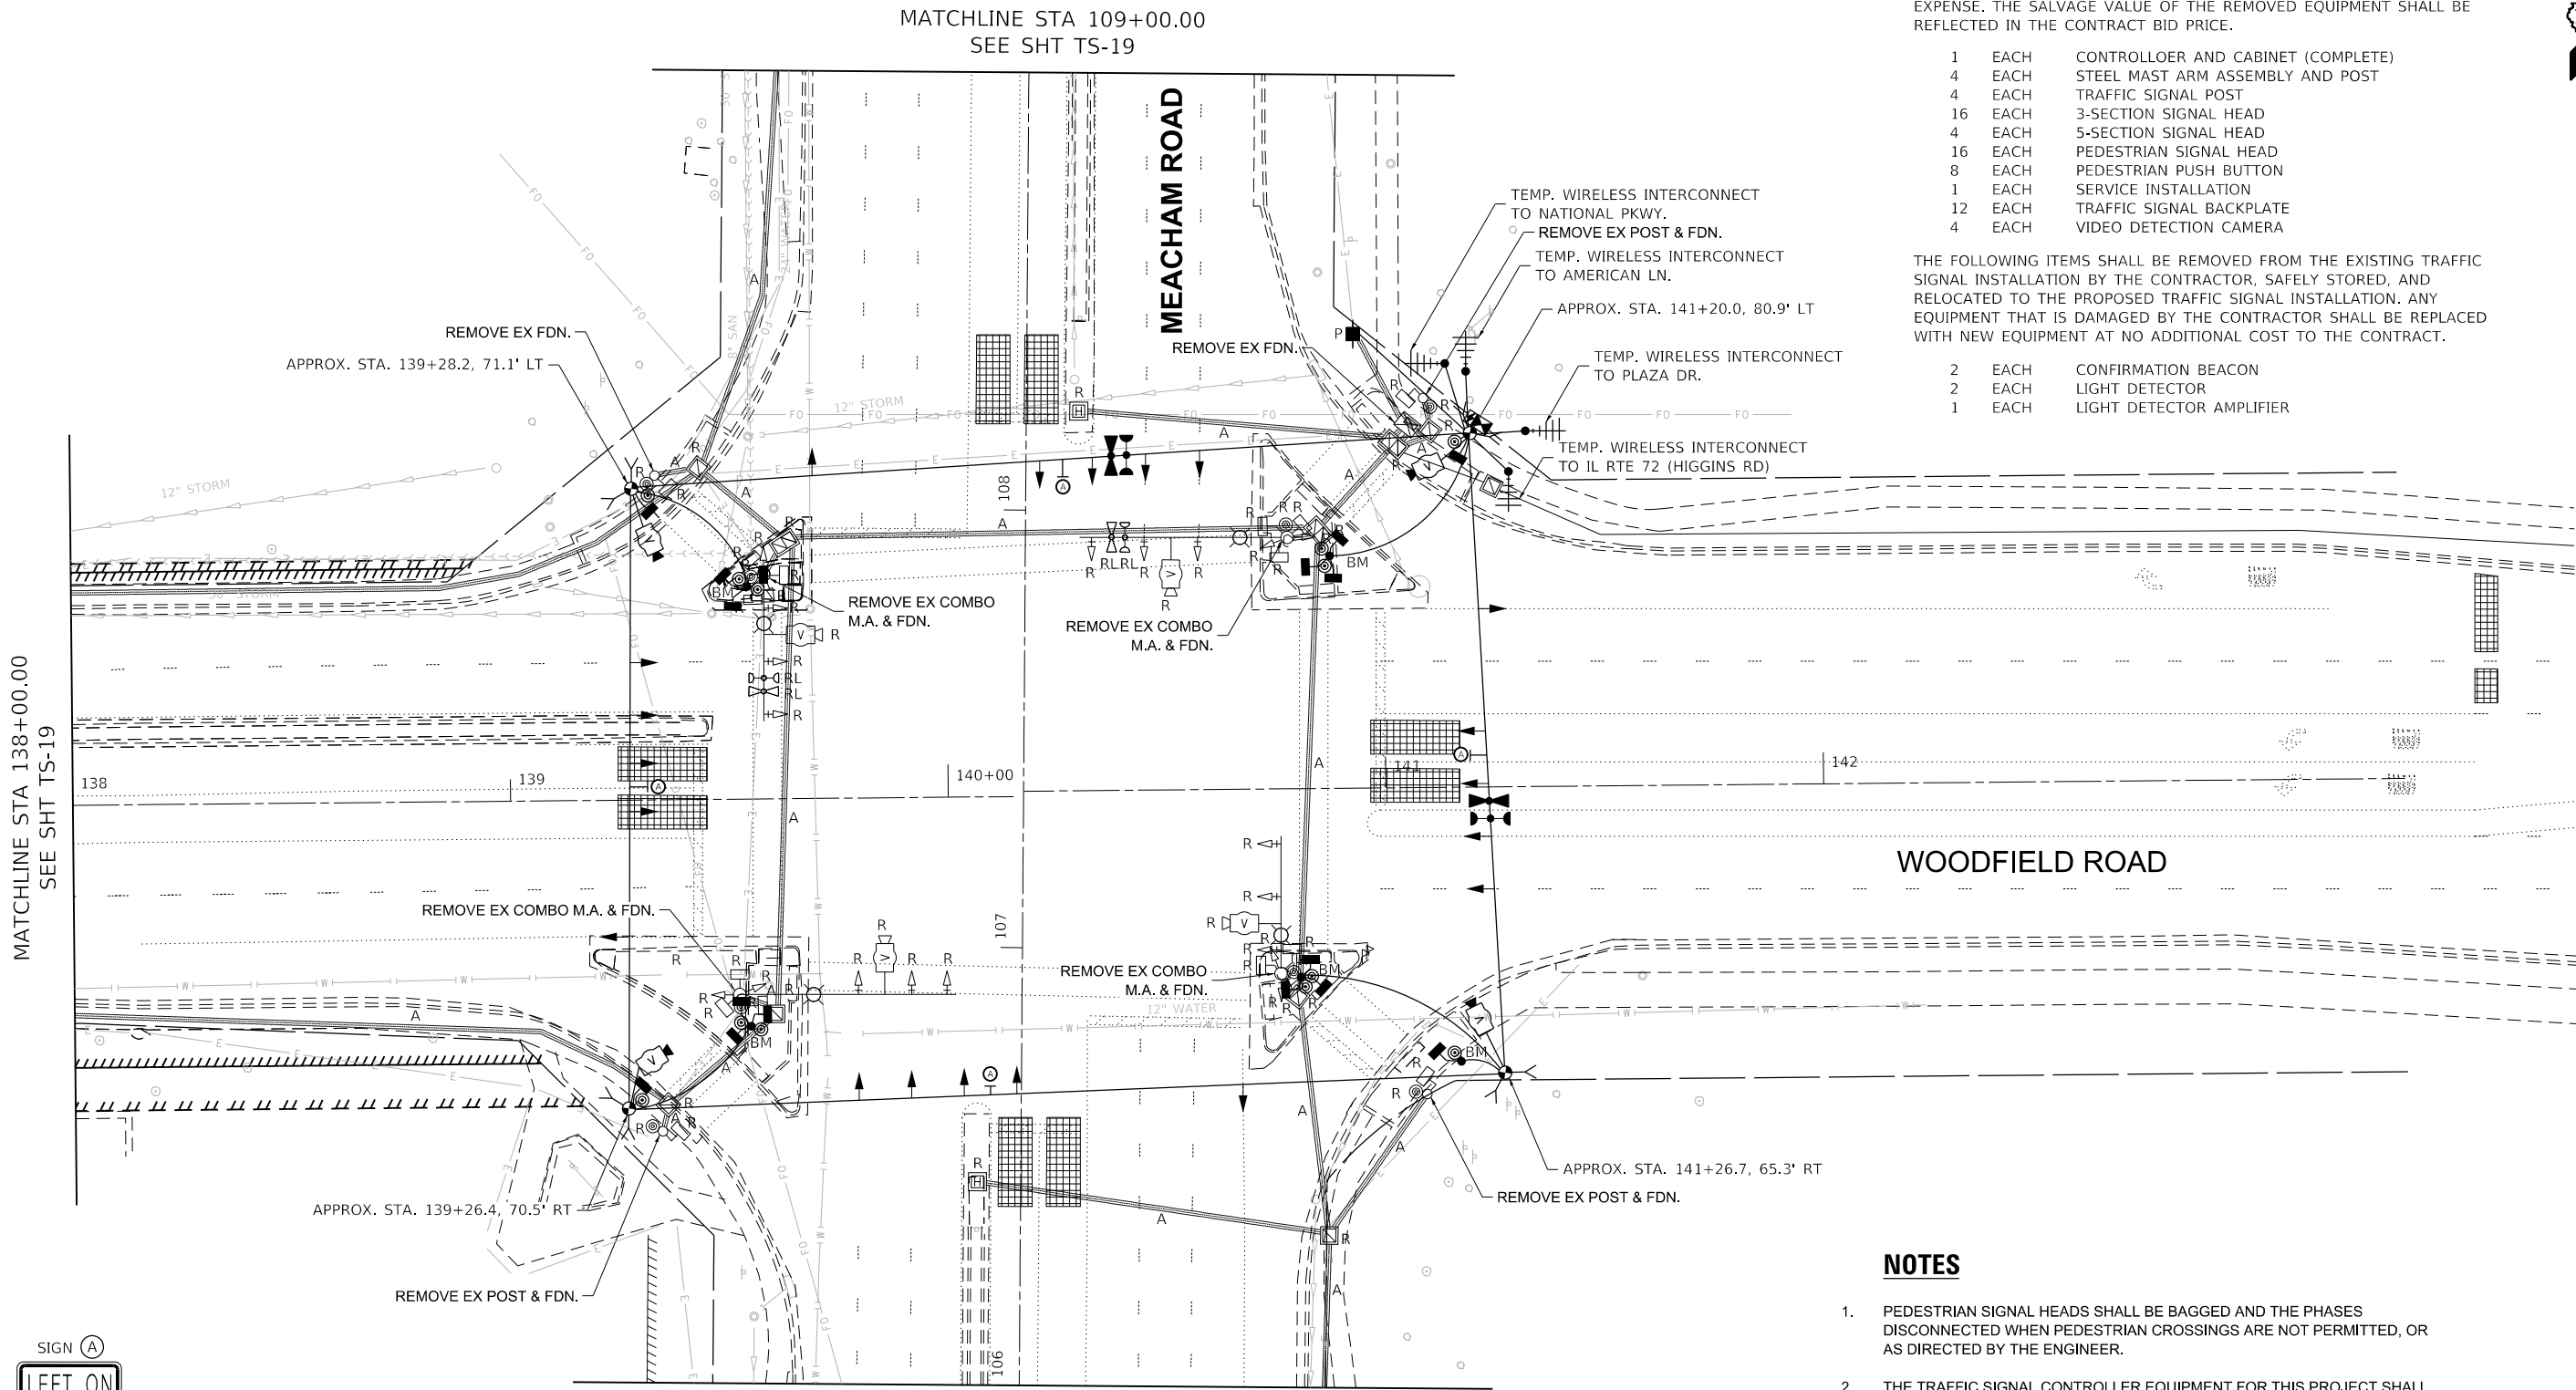 

MATCHLINE STA 138+00.00
SEE SHT TS-19

MATCHLINE STA 109+00.00
SEE SHT TS-19

MATCHLINE STA 106+00.00
SEE SHT TS-19

SIGN (A)

LEFT ON
GREEN
ARROW
ONLY

R10-5
30" X 36"
(4 EACH)

NOTES

- PEDESTRIAN SIGNAL HEADS SHALL BE BAGGED AND THE PHASES DISCONNECTED WHEN PEDESTRIAN CROSSINGS ARE NOT PERMITTED, OR AS DIRECTED BY THE ENGINEER.
- THE TRAFFIC SIGNAL CONTROLLER EQUIPMENT FOR THIS PROJECT SHALL BE "ECONOLITE" TO MATCH THE EXISTING SYSTEM.
- ALL PUSH BUTTONS SHALL BE APS.



MODEL Default
FILE Name: W0119Project2121304_CADD_CADD_01LCADD_SheetsWoodfield-Sht-19_Meacham Rd Temp Signal Plan.dgn




USER NAME = ggedemer	DESIGNED - EEC	REVISED -
	DRAWN - EEC	REVISED -
PLOT SCALE = 40,0000 ' / in.	CHECKED - MG	REVISED -
PLOT DATE = 9/5/2025	DATE - 09/05/2025	REVISED -

STATE OF ILLINOIS
DEPARTMENT OF TRANSPORTATION


TEMPORARY TRAFFIC SIGNAL INSTALLATION AND REMOVAL PLAN
WOODFIELD ROAD AT MEACHAM ROAD

SCALE: 1"=20' SHEET 2 OF 2 SHEETS STA. TO STA.

F.A.U. RTE.	SECTION	COUNTY	TOTAL SHEETS	SHEET NO.
3073	20-00134-00-R5	COOK	166	104
CONTRACT NO. 61L43				
ILLINOIS FED. AID PROJECT				

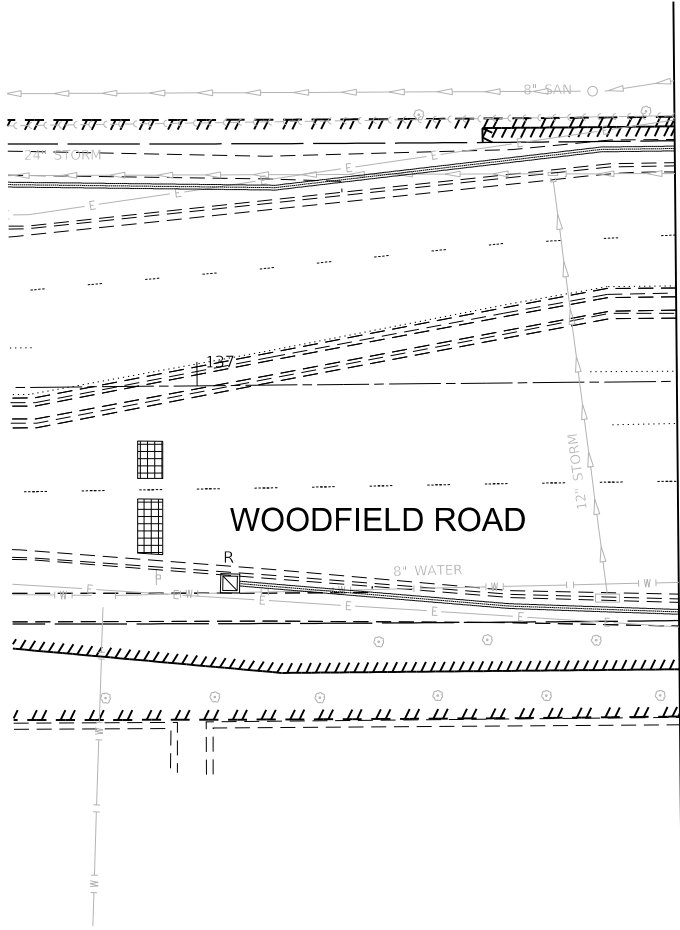

MATCHLINE STA 138+00.00
SEE SHT TS-18

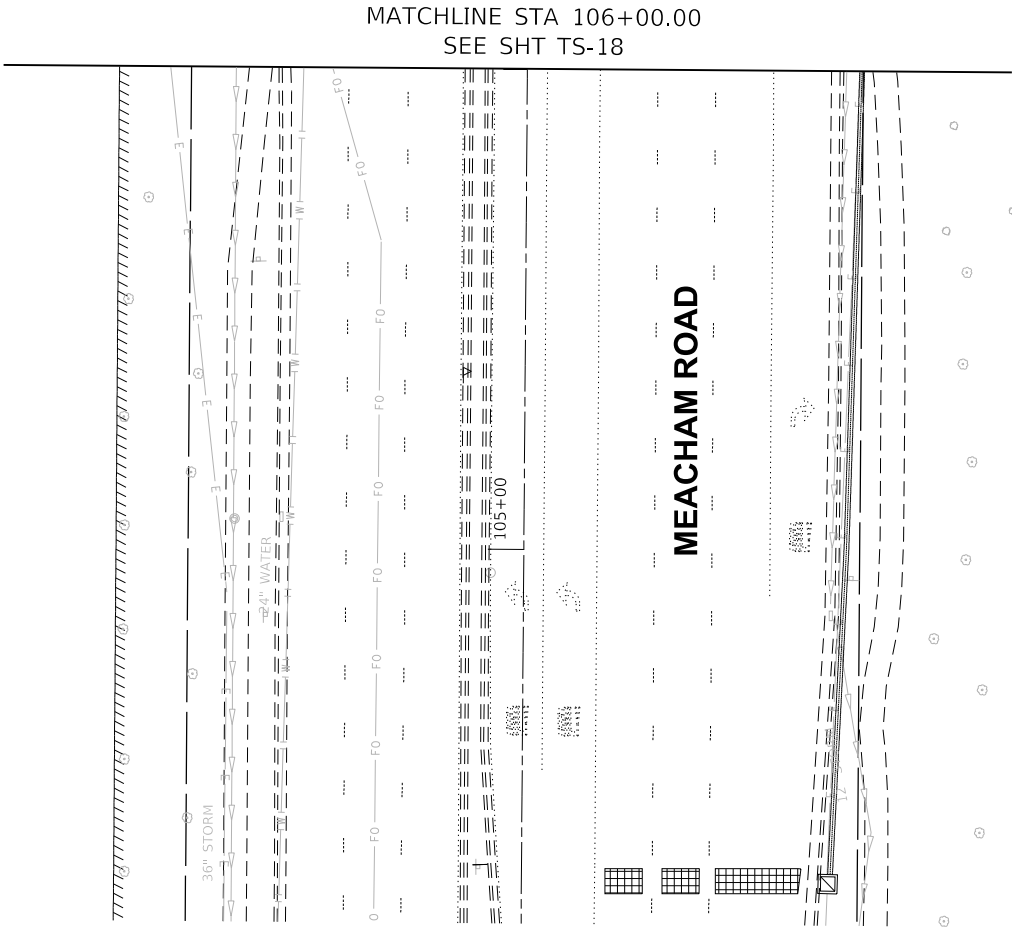

MATCHLINE STA 106+00.00
SEE SHT TS-18



MATCHLINE STA 109+00.00
SEE SHT TS-18



MODEL Default
FILE Name: W:\1\Projects\2121304_CADD_01\CADD_Sheets\Woodfield-Sht-20_Meacham Rd Temp Signal Plan.dgn



USER NAME	= ggedemer	DESIGNED -	EEC	REVISED -	
DRAWN -	EEC	REVIS	EEC	REVISED -	
PLOT SCALE	= 40,0000 ' / in.	CHECKED -	MG	REVISED -	
PLOT DATE	= 9/5/2025	DATE -	09/05/2025	REVISED -	

STATE OF ILLINOIS
DEPARTMENT OF TRANSPORTATION




TEMPORARY TRAFFIC SIGNAL INSTALLATION PLAN – STAGE 1, 1A, 1B, & 1C
WOODFIELD ROAD AT MEACHAM ROAD

SCALE: 1"=20'	SHEET 1 OF 1 SHEETS	STA.	TO STA.
---------------	---------------------	------	---------

F.A.U. RTE.	SECTION	COUNTY	TOTAL SHEETS	SHEET NO.
3073	20-00134-00-R5	COOK	166	105
CONTRACT NO. 61L43				
ILLINOIS		FED. AID PROJECT		

NOTES

 1. PEDESTRIAN SIGNAL HEADS SHALL BE BAGGED AND THE PHASES DISCONNECTED WHEN PEDESTRIAN CROSSINGS ARE NOT PERMITTED, OR AS DIRECTED BY THE ENGINEER.

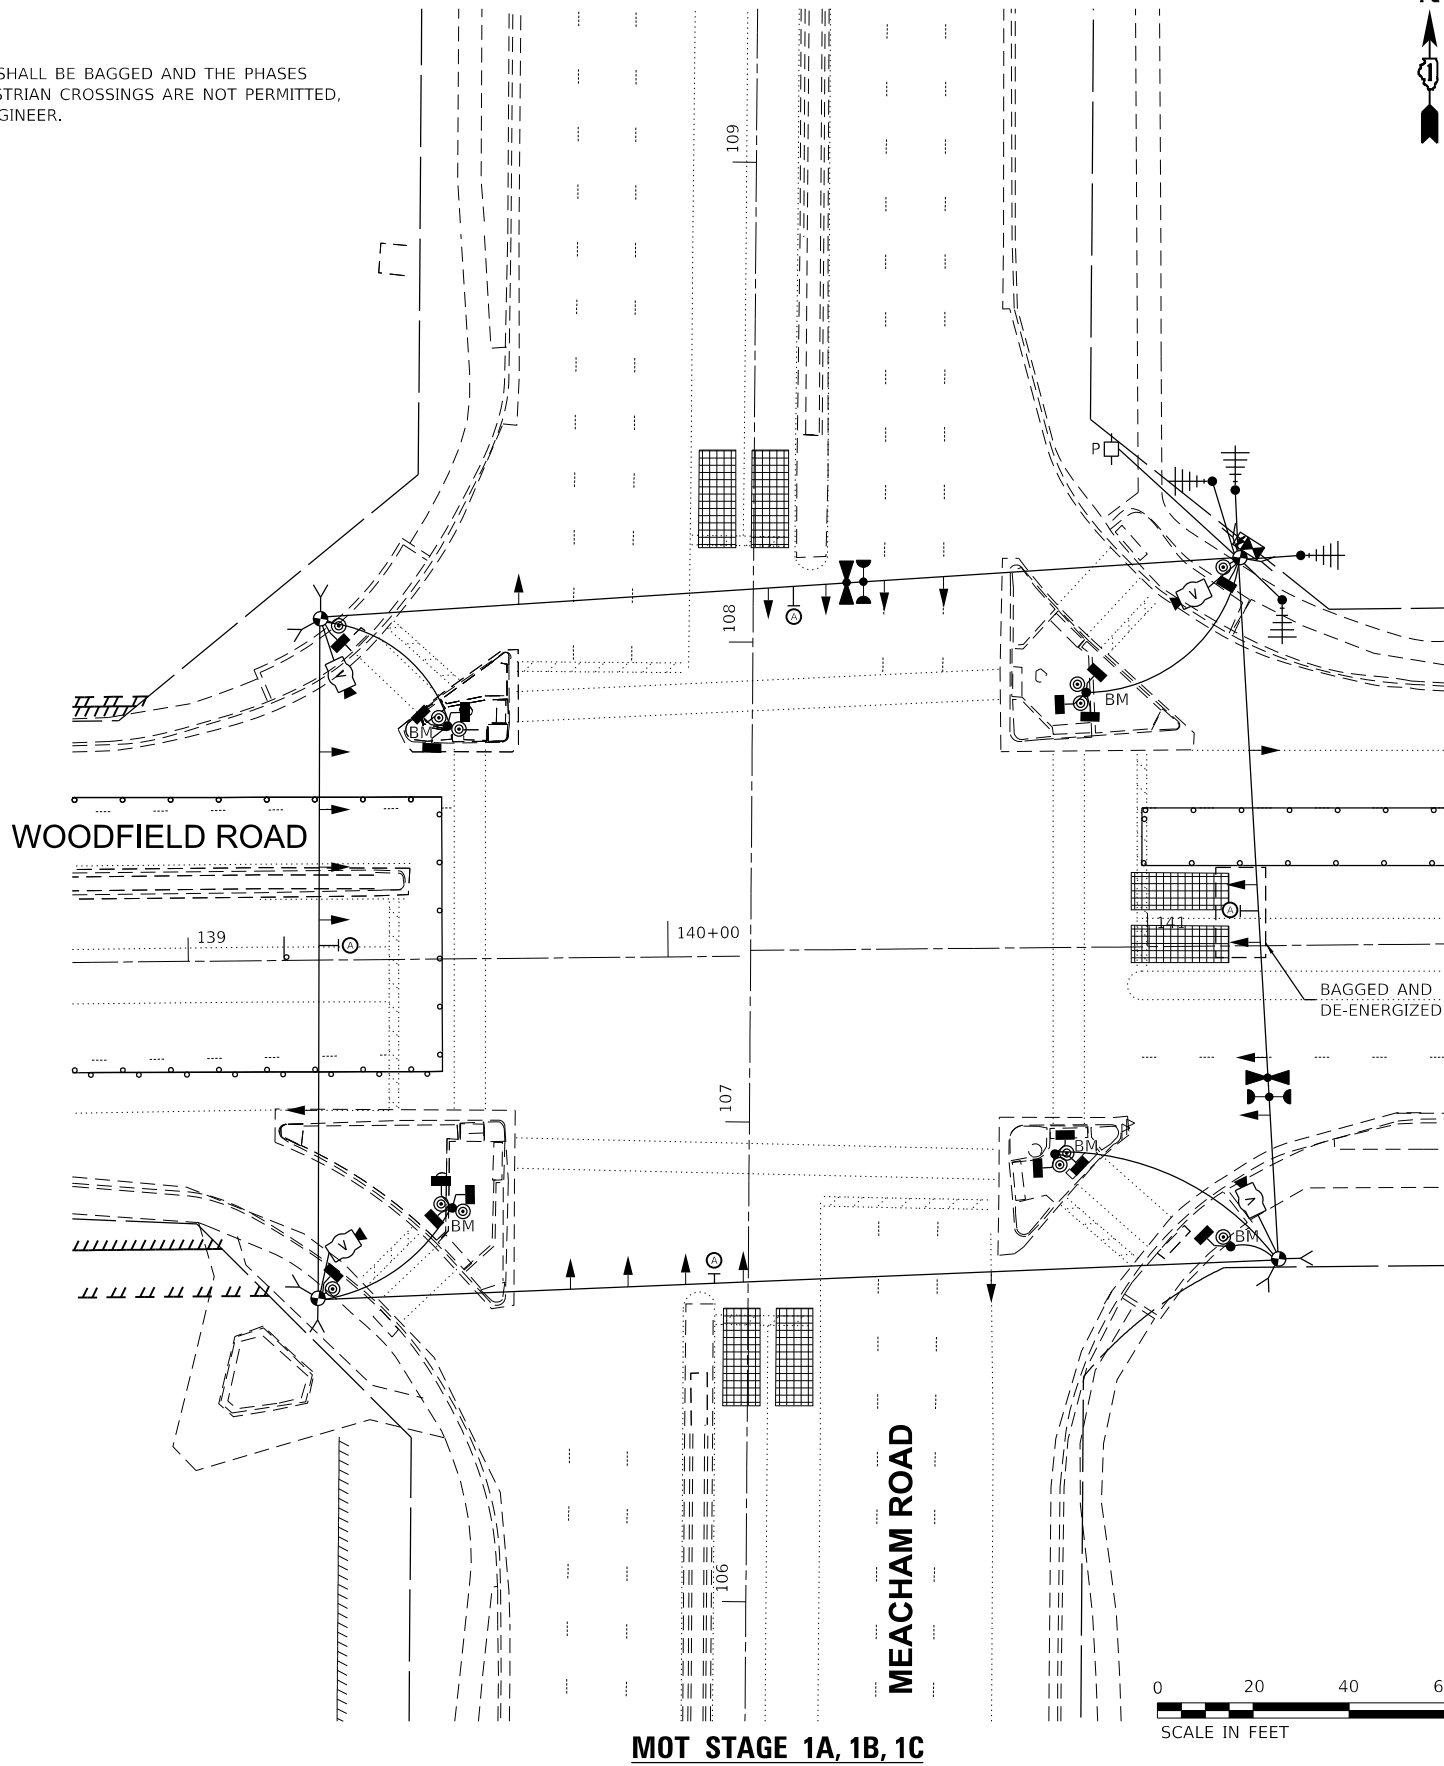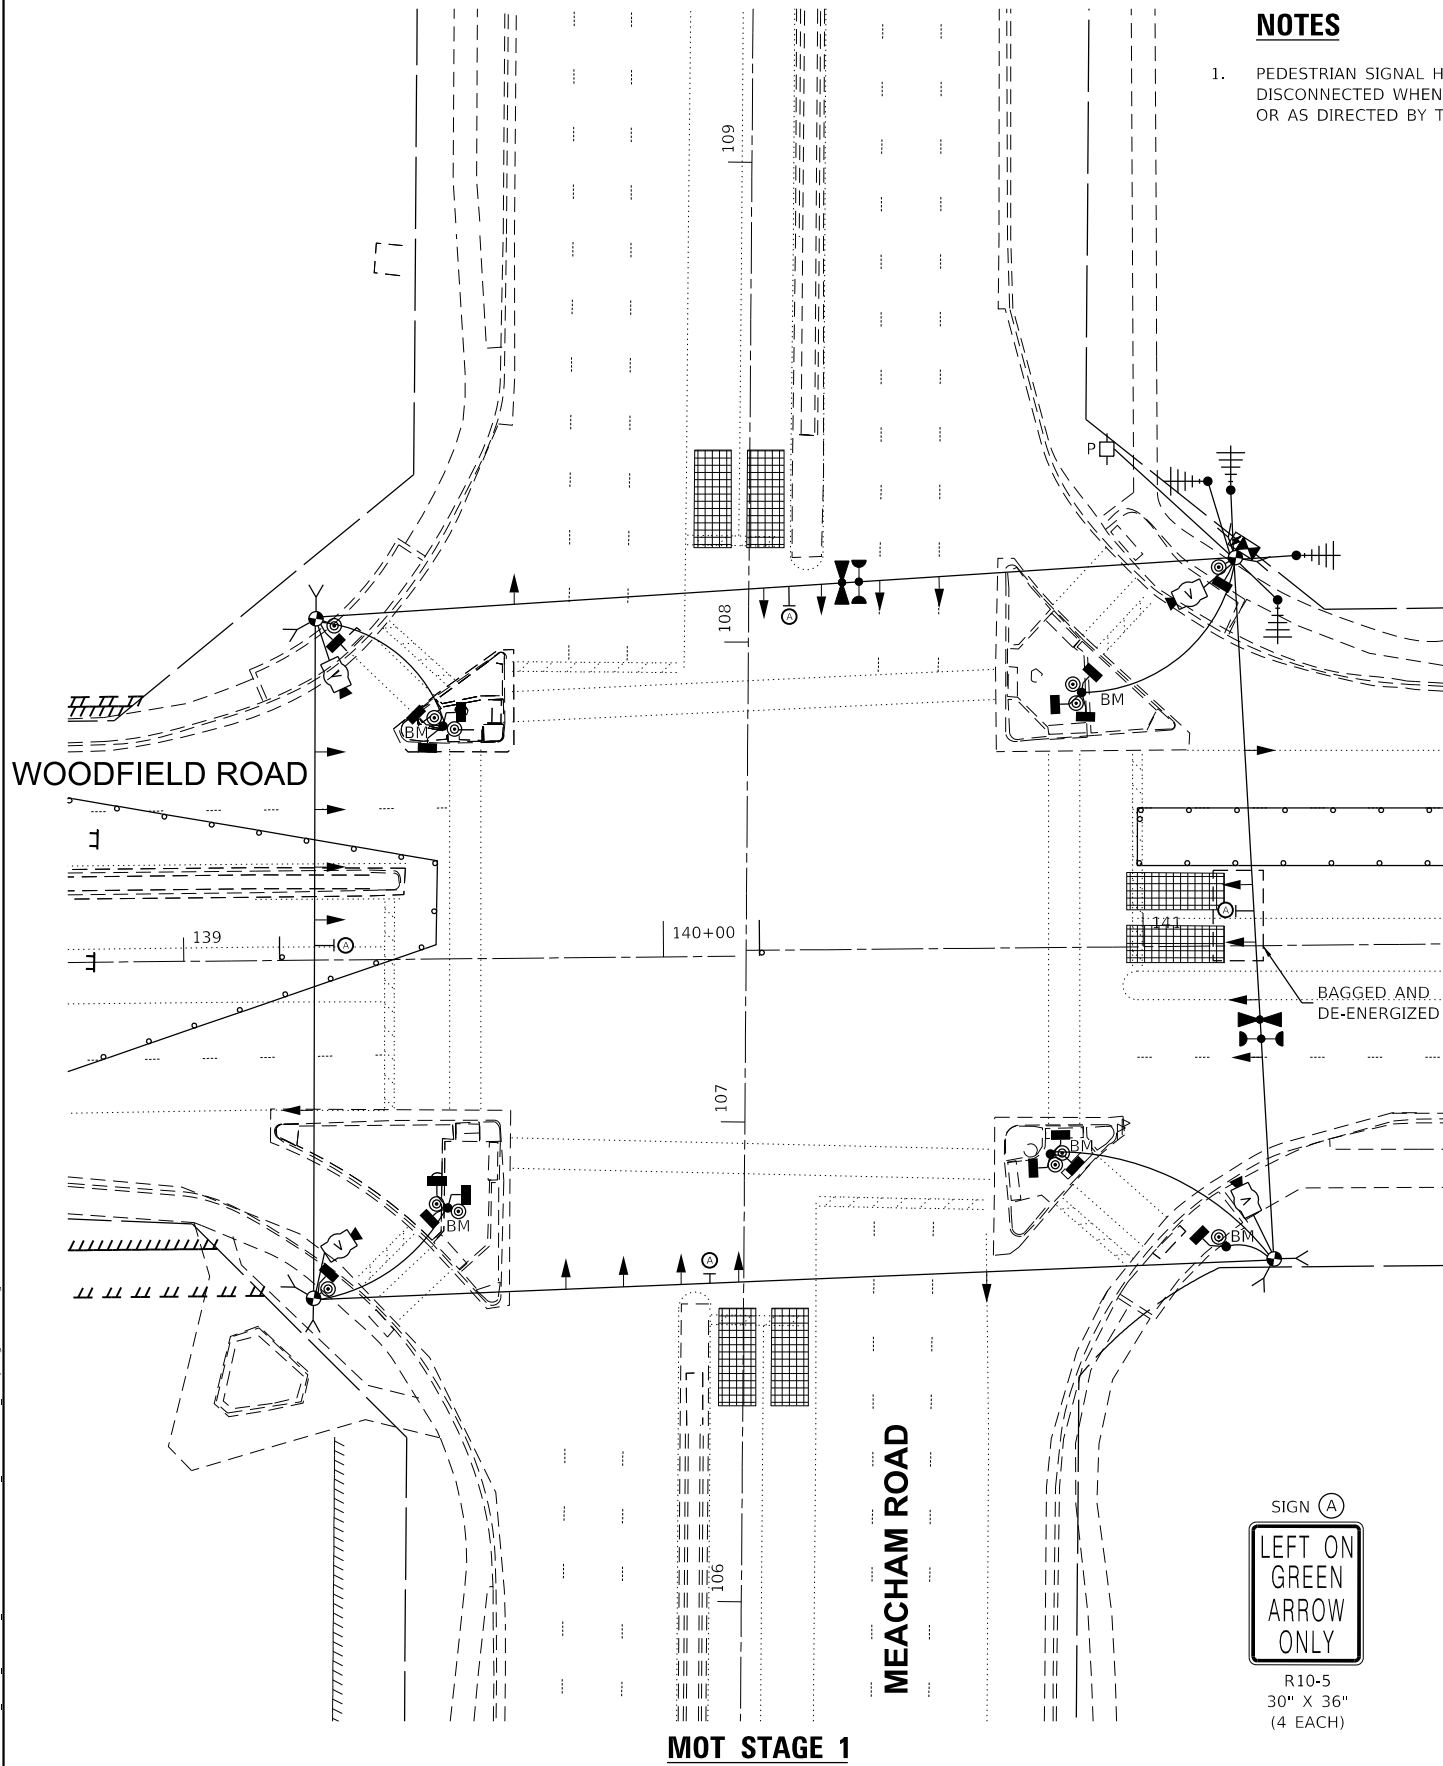

MODEL Default
FILE Name: W:\1\Projects\2121304_CADD_01\CADD_Sheets\Woodfield-Sht-21_Meacham Rd Temp Signal Plan.dgn



USER NAME	= ggedemer
DESIGNED	- EEC
DRAWN	- EEC
PLOT SCALE	= 40,0000 ' / in.
PLOT DATE	= 9/5/2025
CHECKED	- MG
DATE	- 09/05/2025
REVISED	-



MOT STAGE 2 & 2A



R10-5
30" X 36"
(4 EACH)

NOTES

1. PEDESTRIAN SIGNAL HEADS SHALL BE BAGGED AND THE PHASES DISCONNECTED WHEN PEDESTRIAN CROSSINGS ARE NOT PERMITTED, OR AS DIRECTED BY THE ENGINEER.

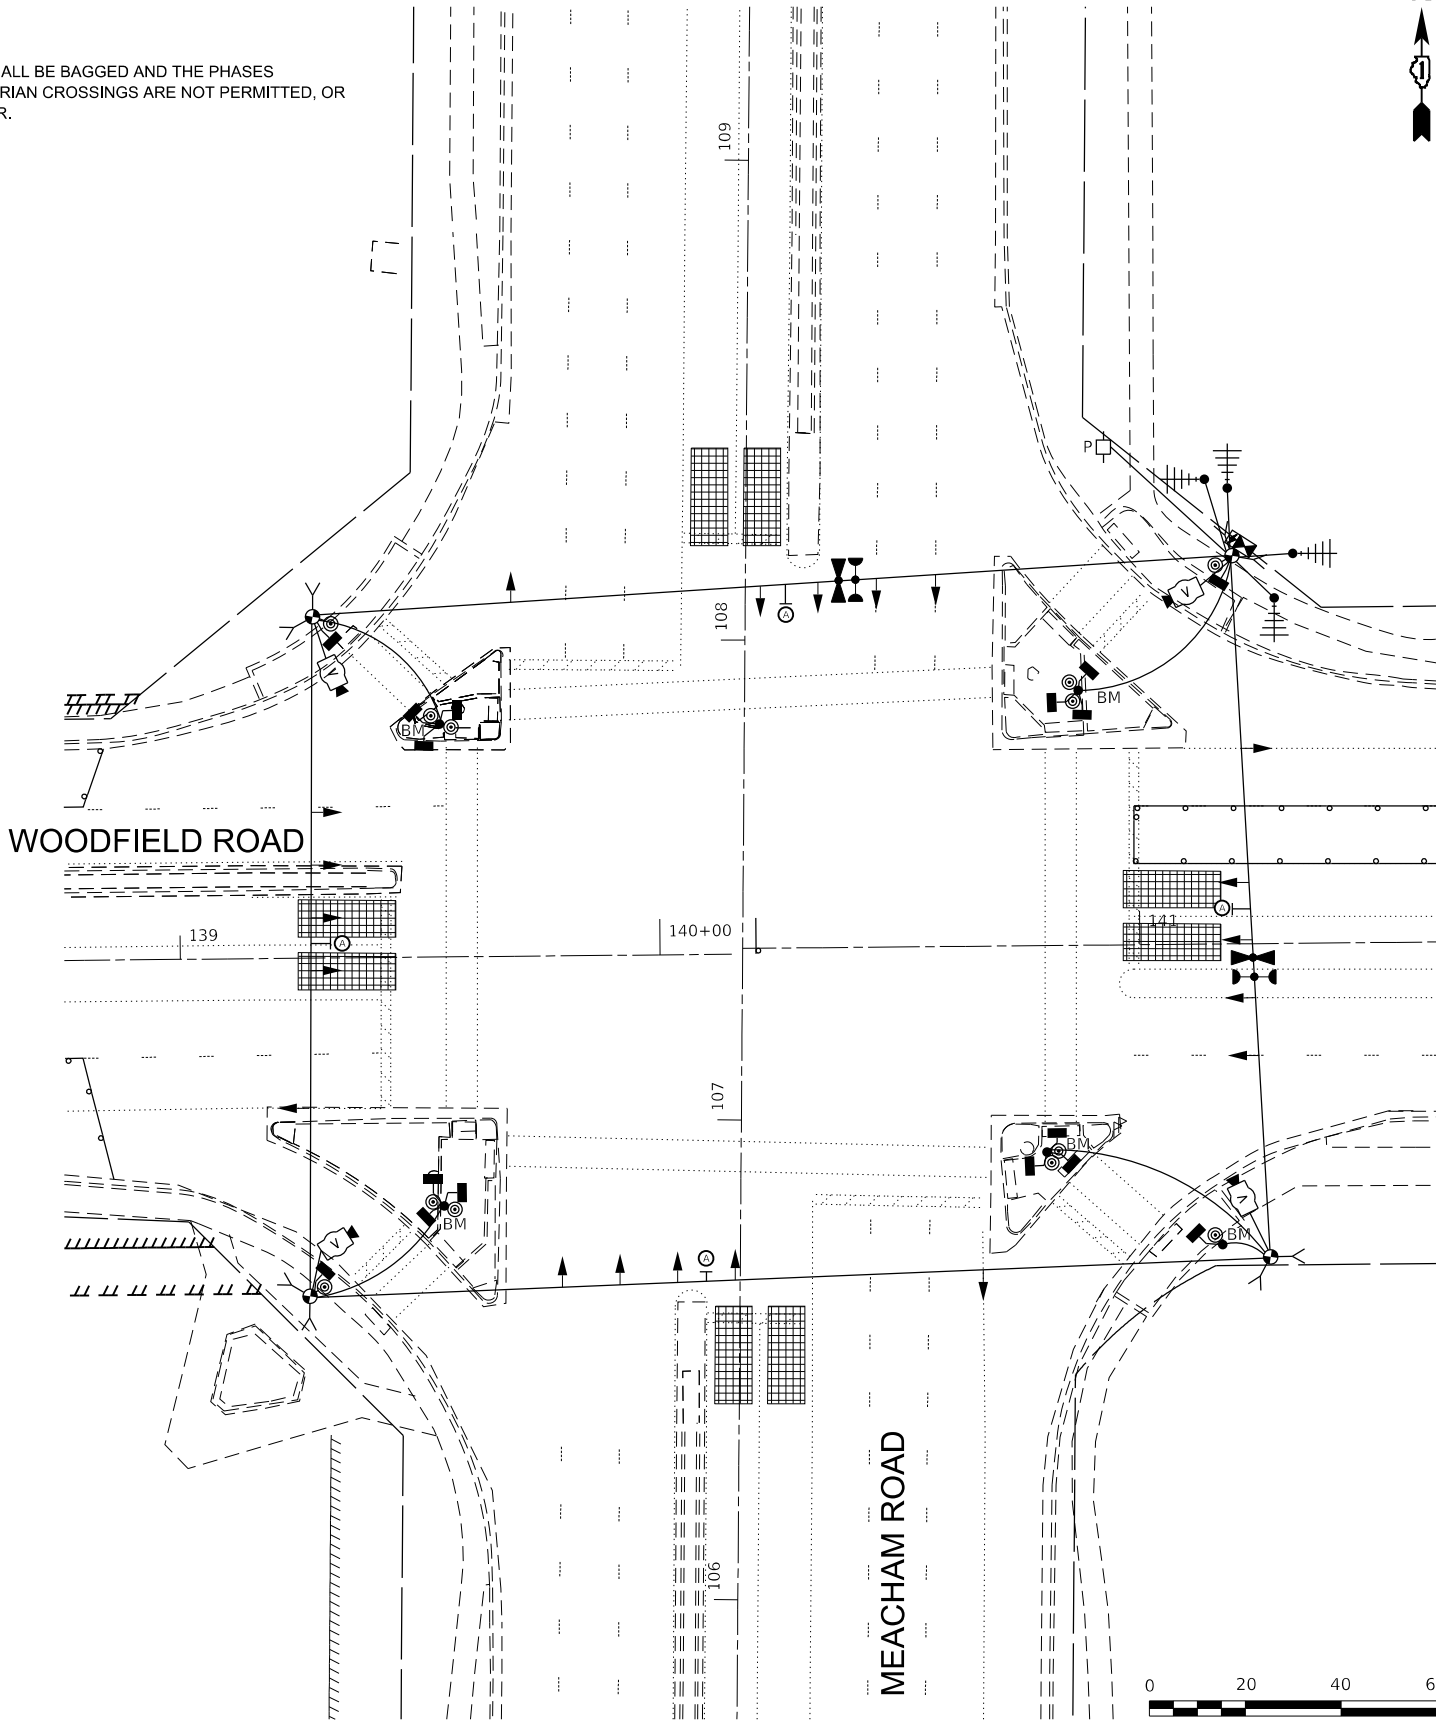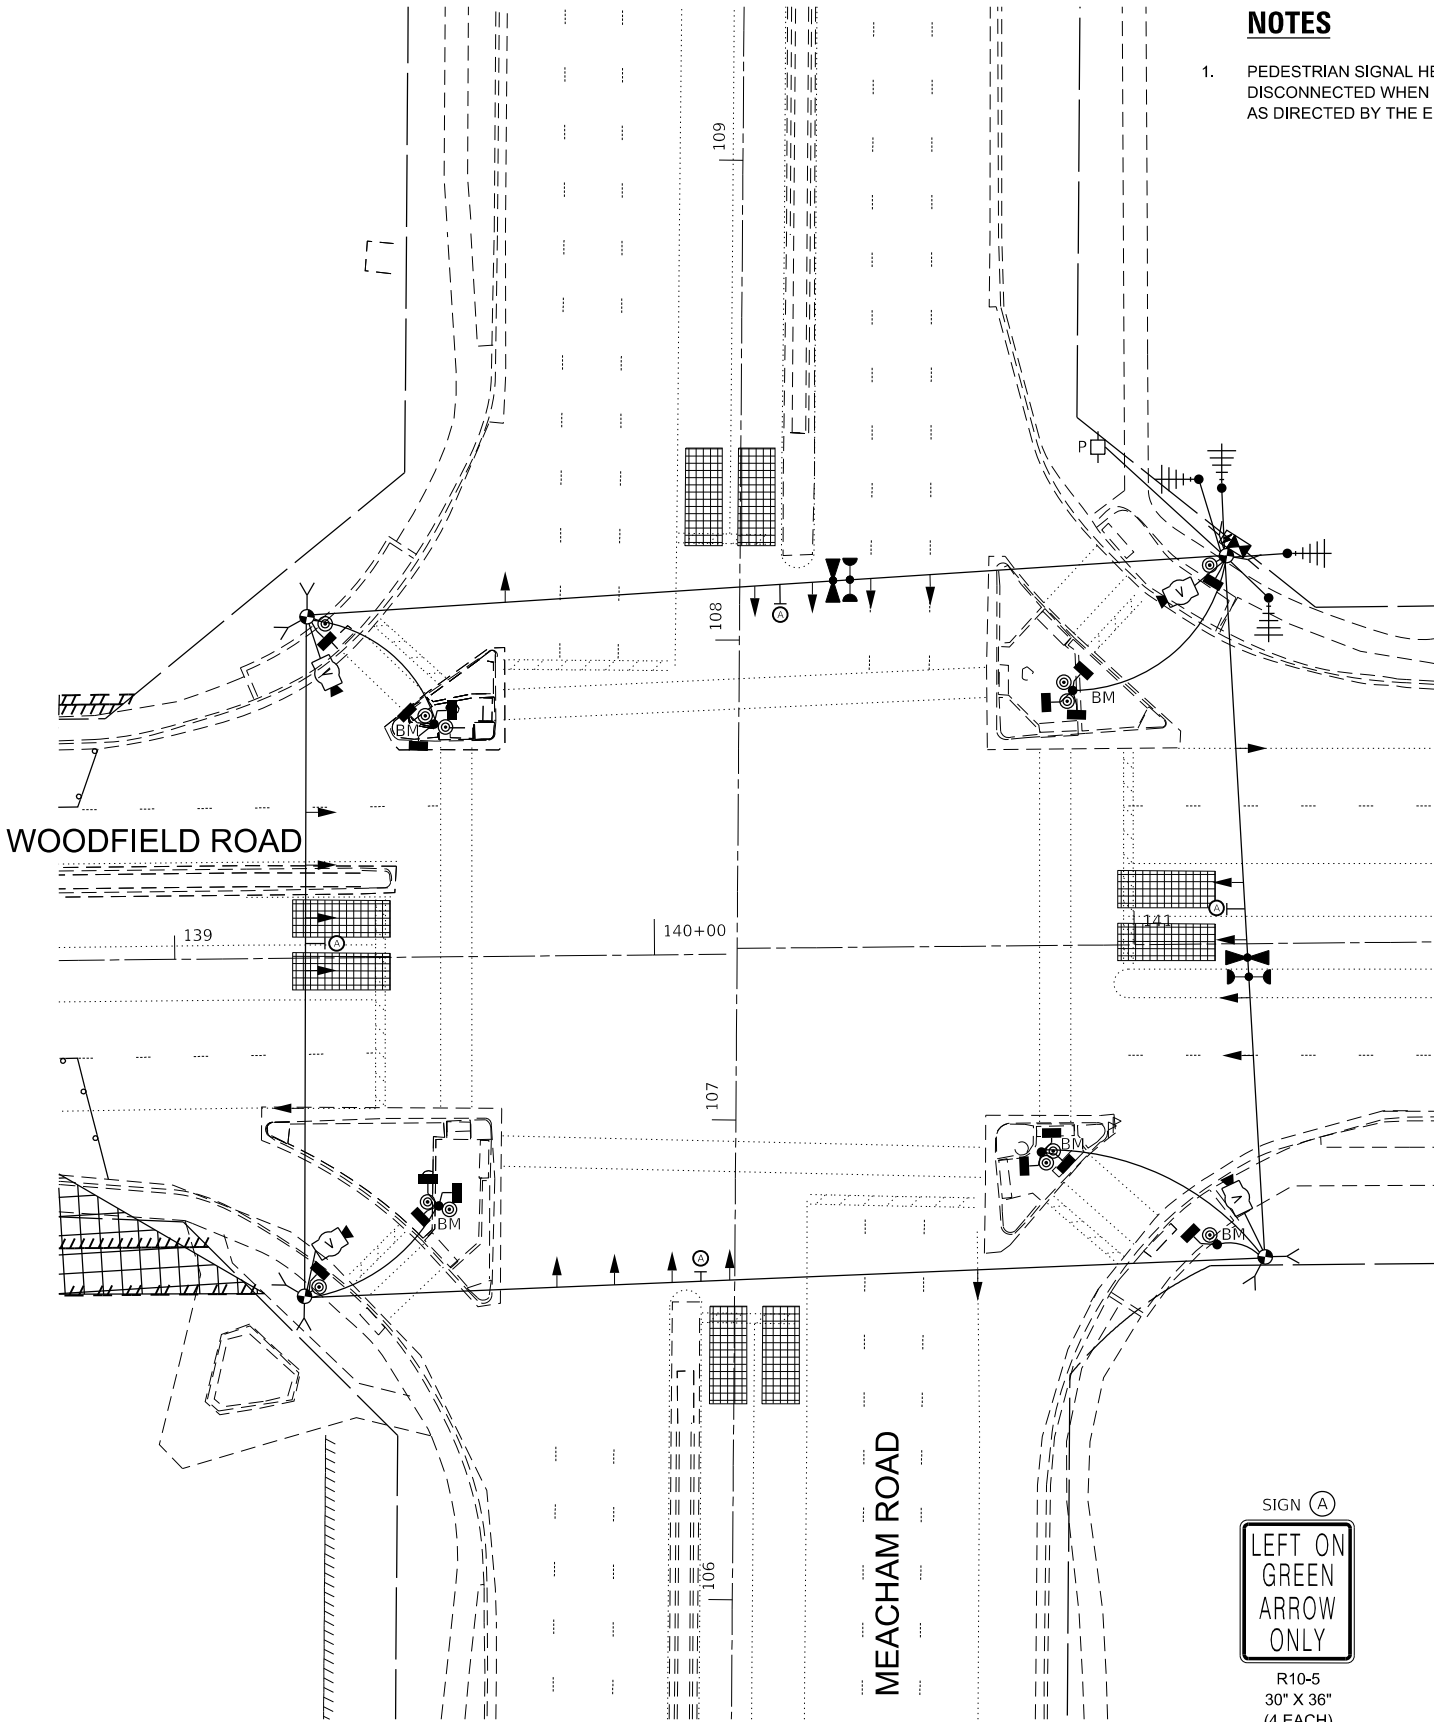

MOT STAGE 2B




STATE OF ILLINOIS
DEPARTMENT OF TRANSPORTATION

TEMPORARY TRAFFIC SIGNAL INSTALLATION PLAN - STAGE 2, 2A, & 2B
WOODFIELD ROAD AT MEACHAM ROAD

SCALE: 1"=20' SHEET 1 OF 1 SHEETS STA. TO STA.

F.A.U. RTE.	SECTION	COUNTY	TOTAL SHEETS	SHEET NO.
3073	20-00134-00-R5	COOK	166	106
CONTRACT NO. 61L43				
ILLINOIS FED. AID PROJECT				

MODEL Default
FILE Name: W011\Projects\2121304_CADD_01\CADD_Sheets\Woodfield-Sht-22_Meacham Rd Temp Signal Plan.dgn

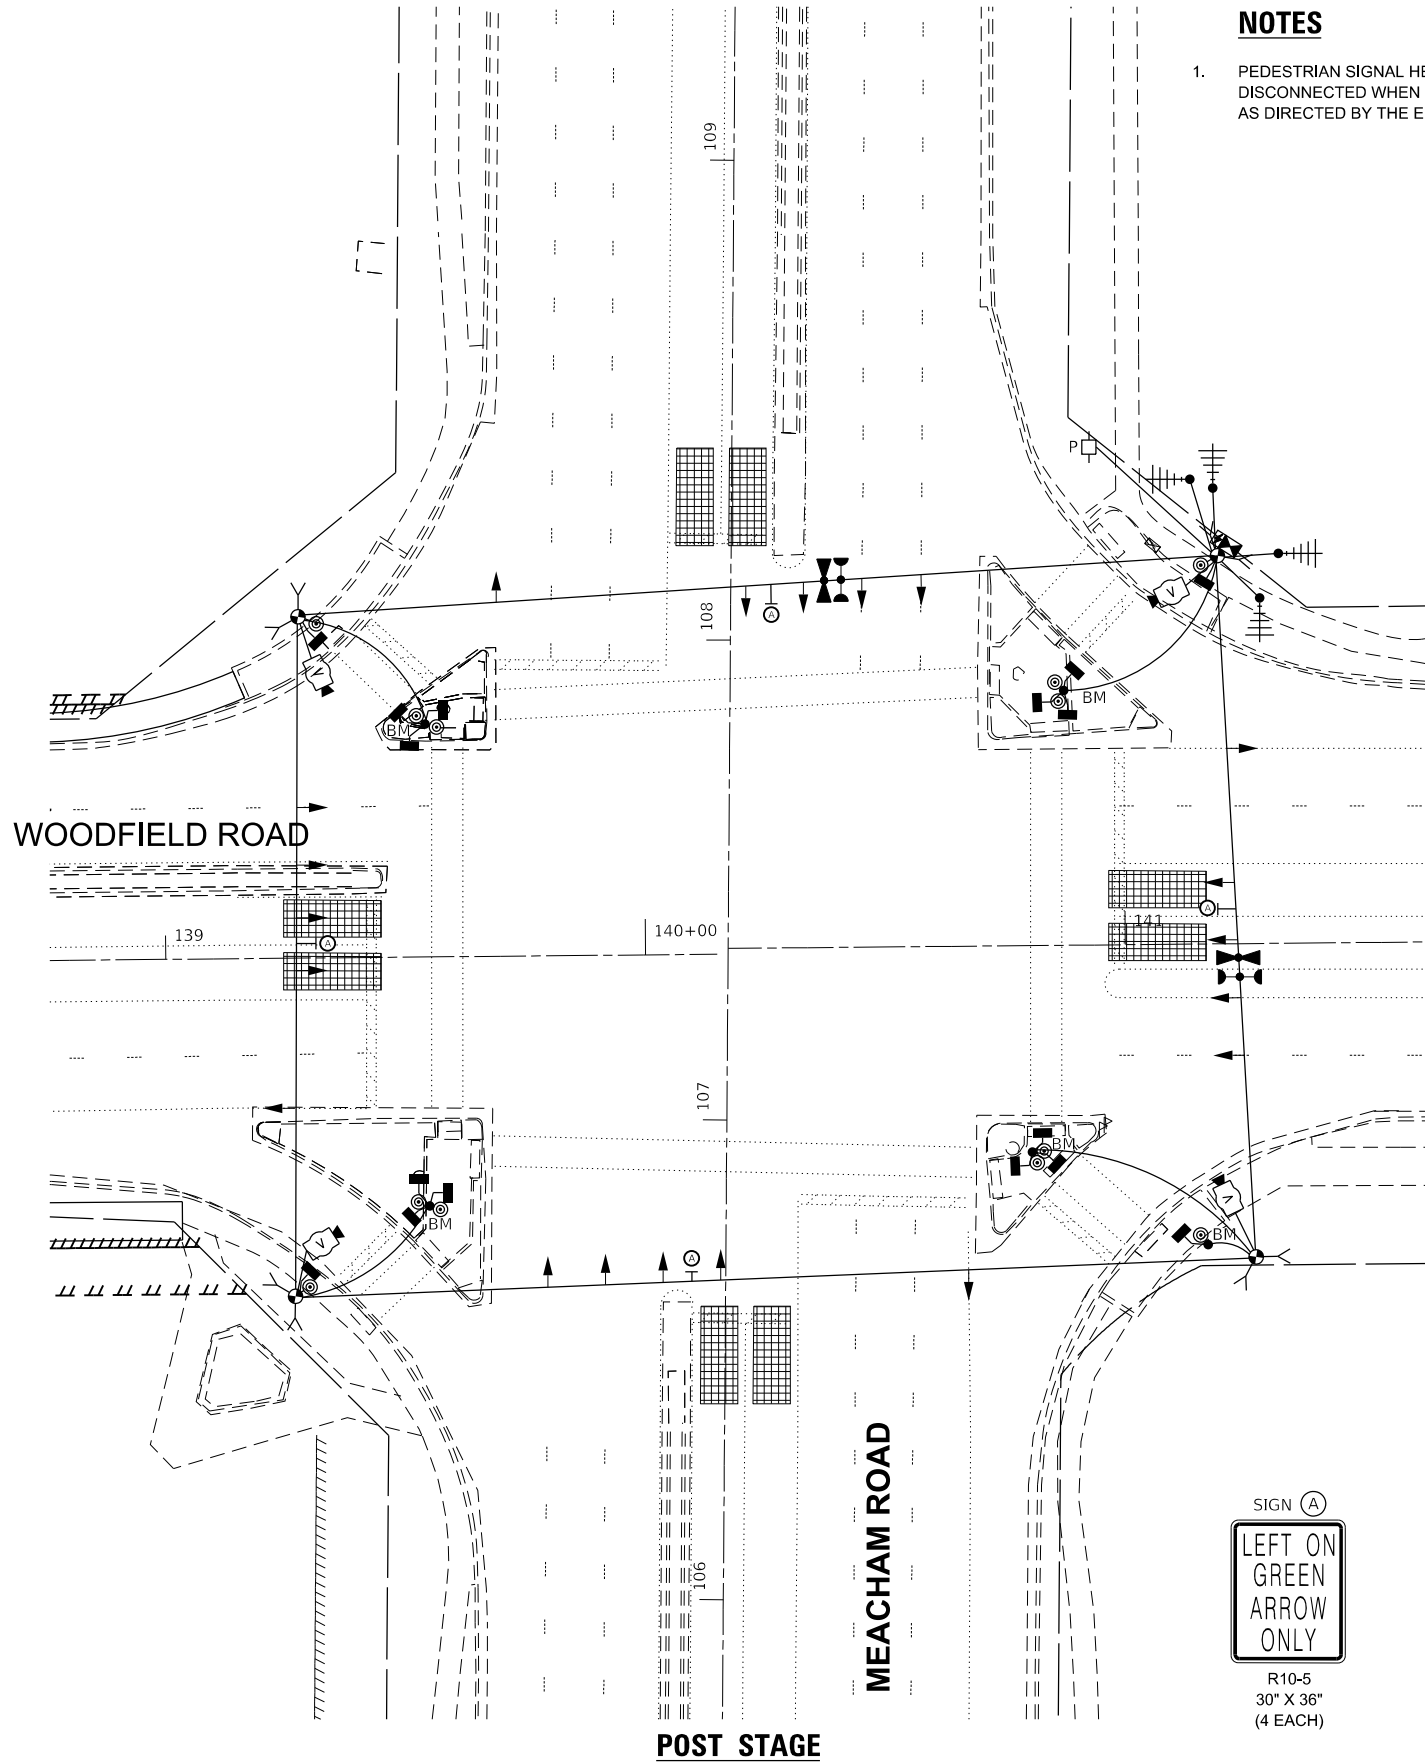


NOTES

1. PEDESTRIAN SIGNAL HEADS SHALL BE BAGGED AND THE PHASES DISCONNECTED WHEN PEDESTRIAN CROSSINGS ARE NOT PERMITTED, OR AS DIRECTED BY THE ENGINEER.



 R10-5
30" X 36"
(4 EACH)



USER NAME = ggedemer	DESIGNED - EEC	REVISED -
	DRAWN - EEC	REVISED -
PLOT SCALE = 40,0000 ' / in.	CHECKED - MG	REVISED -
PLOT DATE = 9/5/2025	DATE - 09/05/2025	REVISED -

STATE OF ILLINOIS
DEPARTMENT OF TRANSPORTATION


TEMPORARY TRAFFIC SIGNAL INSTALLATION PLAN - POST STAGE
WOODFIELD ROAD AT MEACHAM ROAD

SCALE: 1"=20' SHEET 1 OF 1 SHEETS STA. TO STA.

F.A.U. RTE.	SECTION	COUNTY	TOTAL SHEETS	SHEET NO.
3073	20-00134-00-R5	COOK	166	107
CONTRACT NO. 61L43				
ILLINOIS FED. AID PROJECT				

MODEL Default
FILE Name: \\001\projects\2121304_CADD_01\CADD_Sheets\Woodfield-Sht-23_Meacham Rd_Temp Cable Plan.dgn

TEMPORARY CONTROLLER SEQUENCE

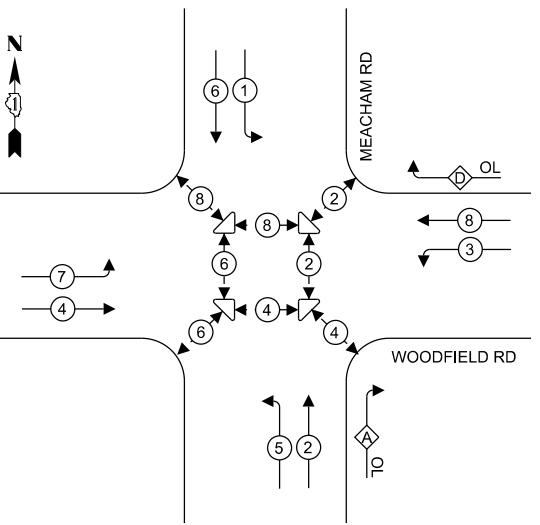


LEGEND:

- ← * → PROTECTED PHASE
- ← * - PROTECTED/PERMITTED PHASE
- ← * → PEDESTRIAN PHASE
- ← * OL → OVERLAP

RIGHT TURN OVERLAP
PHASE DESIGNATION:

OVERLAP LETTER	=	PERMISSIVE PHASE	+	PROTECTED PHASE
A	=	2	+	3
D	=	8	+	1

TEMPORARY EMERGENCY VEHICLE
PREEMPTION SEQUENCE

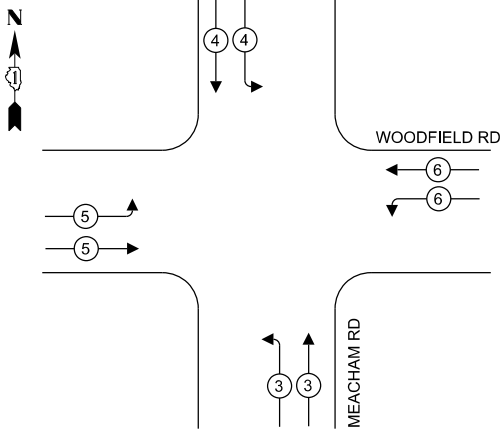

TRAFFIC SIGNAL
ELECTRICAL SERVICE REQUIREMENTS

EQUIPMENT TYPE	QUANTITY	UNIT WATTAGE	TOTAL WATTAGE
SIGNAL HEAD 1 OR 3-SECTION	16	11	176
4-SECTION	-	14	-
5-SECTION	4	13	52
PROGRAMMABLE 3-SECTION	-	22	-
4-SECTION	-	32	-
5-SECTION	-	28	-
PEDESTRIAN SIGNAL	16	15	240
CONTROLLER	1	150	150
MASTER CONTROLLER	-	100	-
UPS	1	25	25
DETECTION RADAR OR VIDEO	1	20	20
BLANK-OUT SIGN	-	25	-
NETWORK SWITCH II OR III	-	35	-
CELLULAR MODEM	-	15	-
TOTAL UPS SIZING			663
UPS CHARGING	1	225	225
BATTERY HEATER MAT	1	180	180
CABINET HEATER	1	200	200
FLASHER	-	15	-
LED STREET NAME SIGN	-	120	-
LUMINAIRE	-	240	-
TOTAL SERVICE WIRE SIZING			1,268

ENERGY COSTS TO:

VILLAGE OF SCHAUMBURG

101 SCHAUMBURG COURT
SCHAUMBURG, IL 60193

ENERGY SUPPLY: CONTACT: ARTURO SALDIVAR

PHONE:

COMPANY: COMED

ACCOUNT NUMBER: XXXXX-XXXXX

TOWER ACCOUNT NUMBER: 0245068017

SINGH
SINGH & ASSOCIATES, INC.
CONSULTING ENGINEERS

USER NAME	= ggedemer
PLOT SCALE	= 2,000' / in.
PLOT DATE	= 9/5/2025

DESIGNED	-	EEC	REVISED	-
DRAWN	-	EEC	REVISED	-
CHECKED	-	MG	REVISED	-
DATE	-	09/05/2025	REVISED	-


STATE OF ILLINOIS
DEPARTMENT OF TRANSPORTATION

TEMPORARY CABLE PLAN, PHASE DESIGNATION DIAGRAM, AND
EMERGENCY VEHICLE PREEMPTION SEQUENCE
WOODFIELD ROAD AT MEACHAM ROAD

SCALE: NTS

SHEET 1 OF 1 SHEETS STA. TO STA.

F.A.U. RTE.	SECTION	COUNTY	TOTAL SHEETS	SHEET NO.
3073	20-00134-00-R5	COOK	166	108
CONTRACT NO. 61L43				
ILLINOIS FED. AID PROJECT				

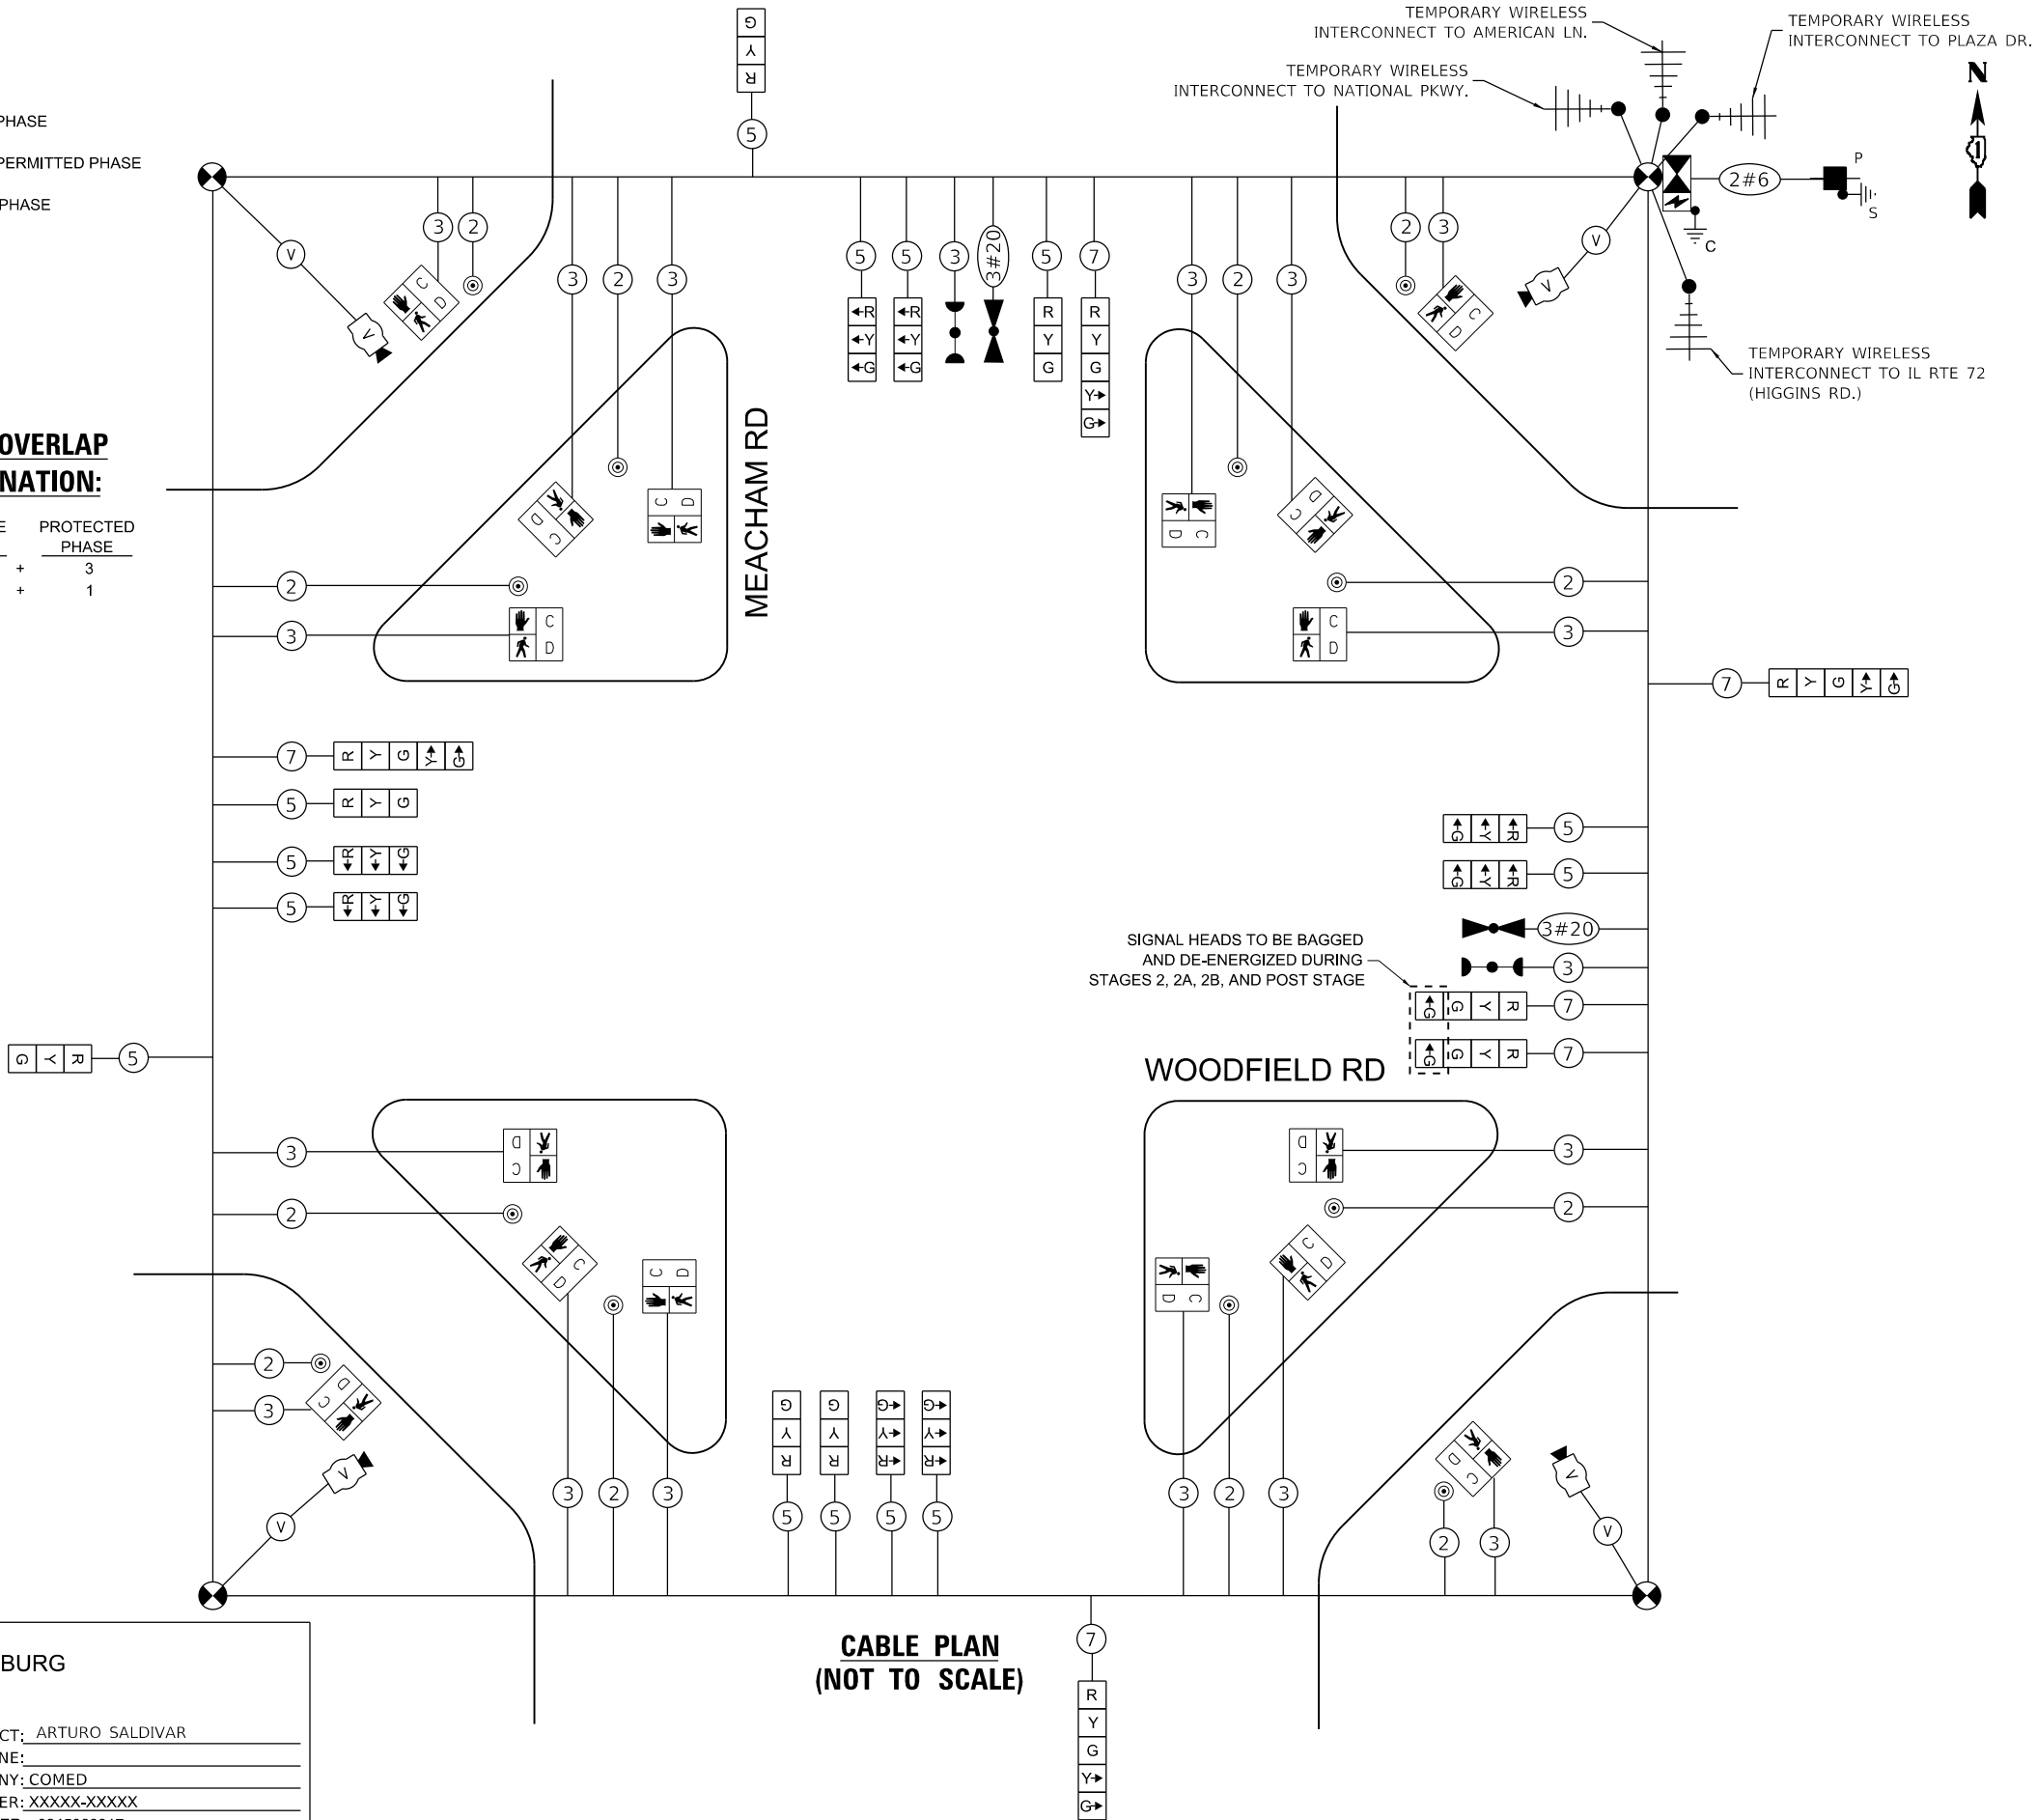

MODEL Default
FILE Name: W:\1\Projects\2121304_CADD_01\CADD_Sheets\Woodfield-Sht-24_Meacham Rd_Prop_Signal_Plan.dgn



USER NAME = jturk	DESIGNED - EEC	REVISED -
	DRAWN - EEC	REVISED -
PLOT SCALE = 40,0000 ' / in.	CHECKED - MG	REVISED -
PLOT DATE = 9/8/2025	DATE - 09/05/2025	REVISED -

STATE OF ILLINOIS
DEPARTMENT OF TRANSPORTATION


TRAFFIC SIGNAL MODERNIZATION PLAN (SHEET 1 OF 2)
WOODFIELD ROAD AT MEACHAM ROAD

SCALE: 1"=20' SHEET 1 OF 2 SHEETS STA. TO STA.

F.A.U. RTE.	SECTION	COUNTY	TOTAL SHEETS	SHEET NO.
3073	20-00134-00-R5	COOK	166	109
CONTRACT NO. 61L43				
		ILLINOIS	FED. AID PROJECT	

NOTES

1. APS SHALL BE PLACED PARALLEL TO THE CORRESPONDING CROSSWALK.
2. ALL PUSH BUTTONS SHALL BE APS.
3. ALL MAST ARM MOUNTED SIGNAL HEADS SHALL BE CENTERED ON THE LANES.
4. THERE SHALL BE A MINIMUM OF 4' SIDEWALK CLEARANCE NEXT TO TRAFFIC SIGNAL FOUNDATIONS TO BE ADA COMPLIANT.
5. VIDEO DETECTION SYSTEMS SHALL BE MOUNTED ON RISER BRACKETS AT THE LENGTH DETERMINED BY THE MANUFACTURER, FINAL CAMERA LOCATIONS SHALL BE OPTIMAL TO MINIMIZE OCCLUSION ON FALSE CALLS FROM TRAFFIC ADJACENT LANES.

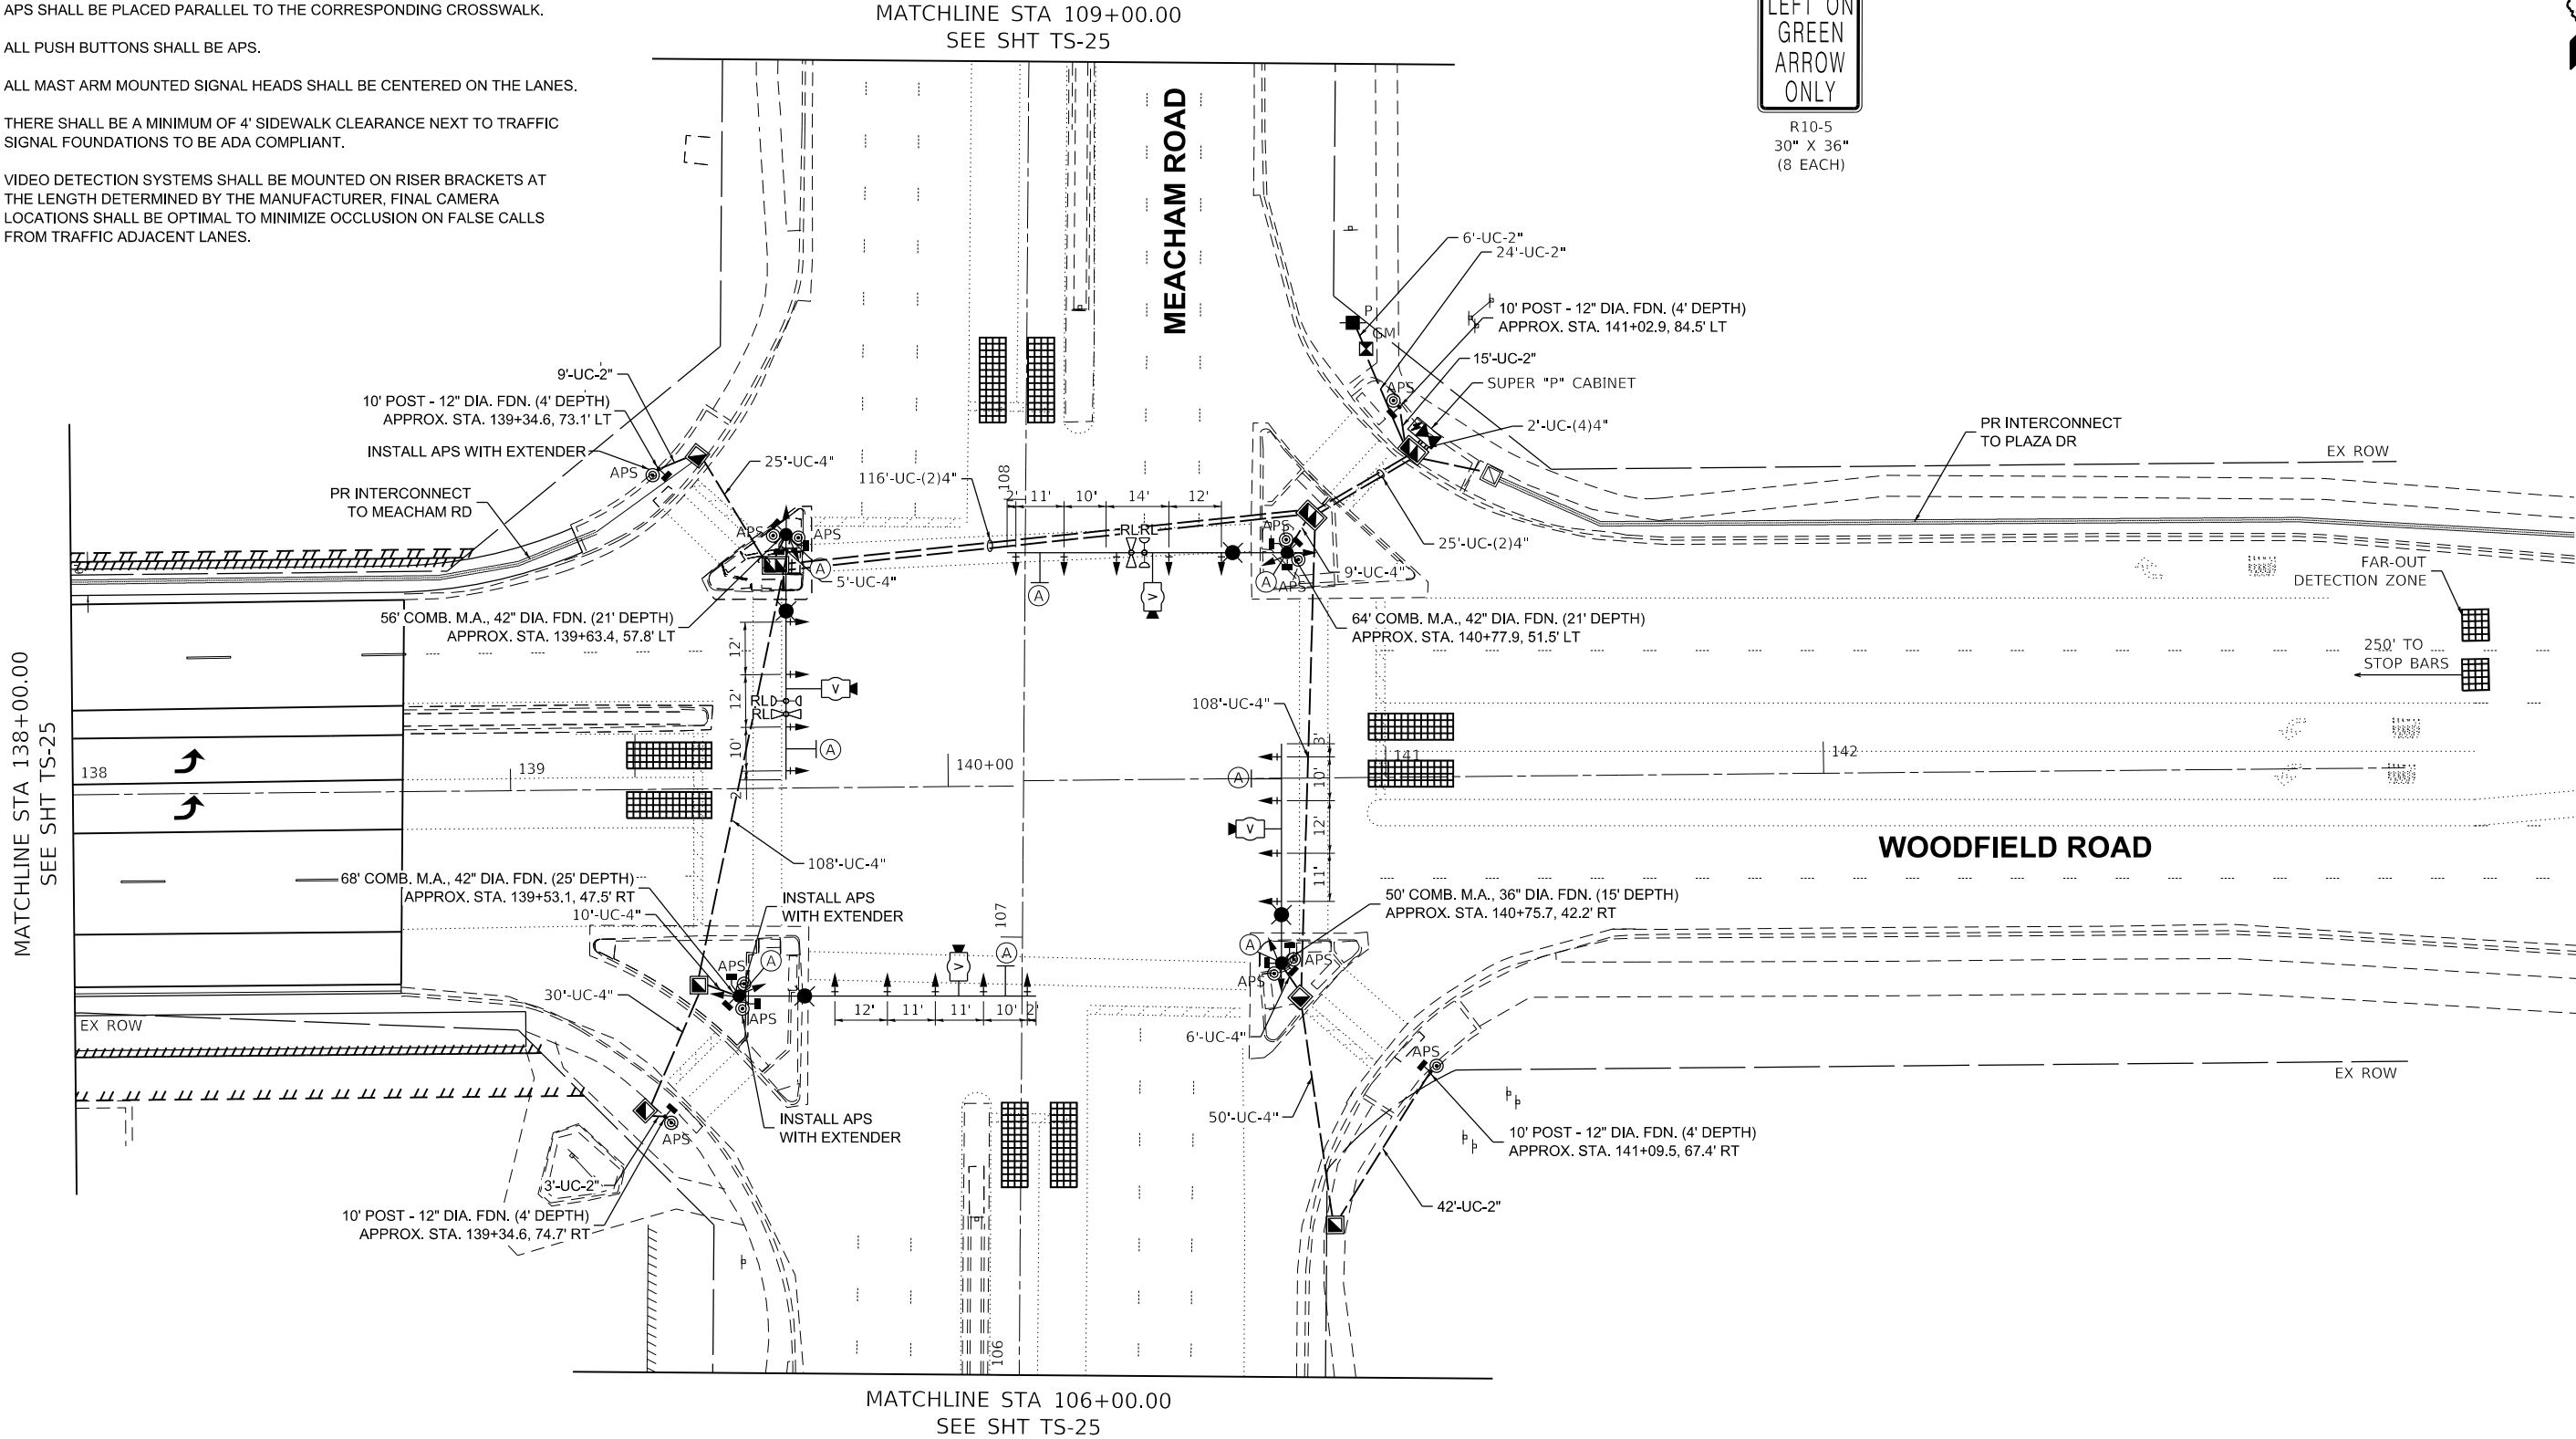

MODEL Default
FILE Name: W011\Project\2121304_CADD_01\CADD_Sheets\Woodfield-Sht-25_Meacham Rd Prop Signal Plan.dgn






USER NAME = ggedemer	DESIGNED - EEC	REVISED -
	DRAWN - EEC	REVISED -
PLOT SCALE = 40,0000 ' / in.	CHECKED - MG	REVISED -
PLOT DATE = 9/5/2025	DATE - 09/05/2025	REVISED -

STATE OF ILLINOIS
DEPARTMENT OF TRANSPORTATION


TRAFFIC SIGNAL MODERNIZATION PLAN (SHEET 2 OF 2) WOODFIELD ROAD AT MEACHAM ROAD			
SCALE: 1"=20'	SHEET 2	OF 2 SHEETS	STA. TO STA.

F.A.U. RTE.	SECTION	COUNTY	TOTAL SHEETS	SHEET NO.
3073	20-00134-00-R5	COOK	166	110
CONTRACT NO. 61L43				
ILLINOIS FED. AID PROJECT				

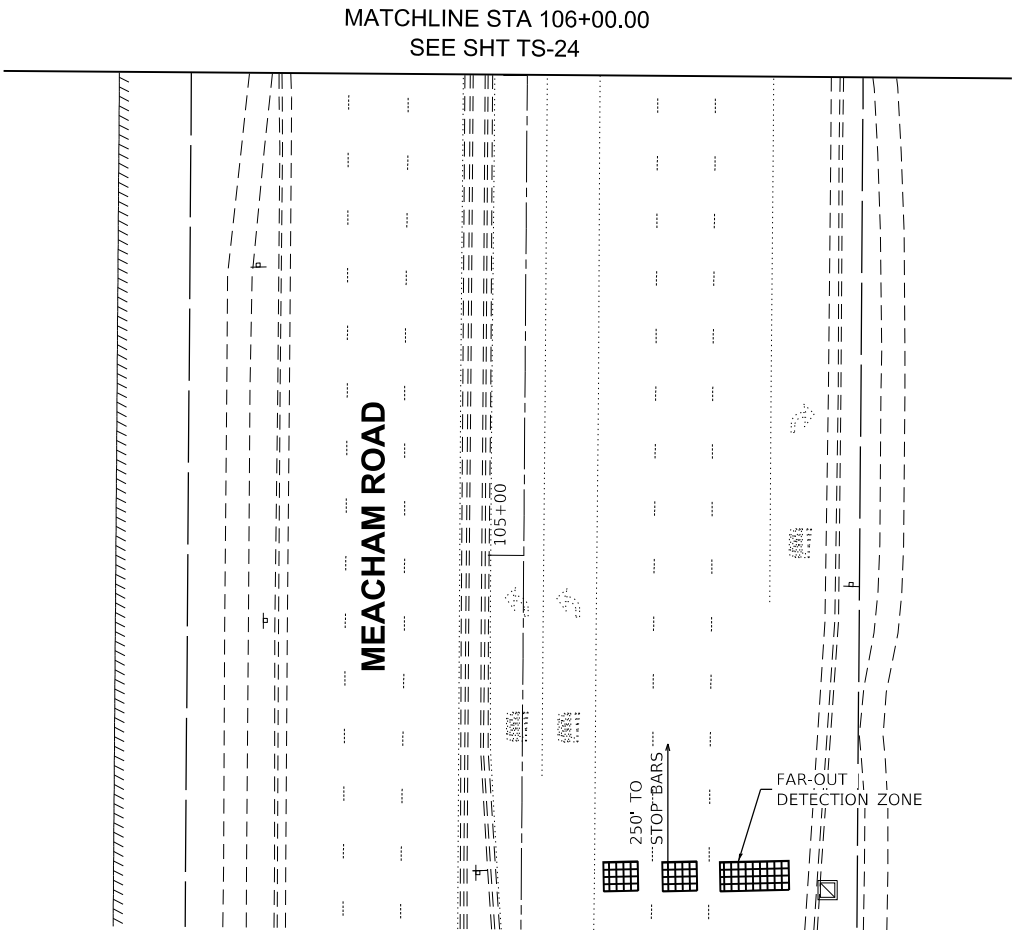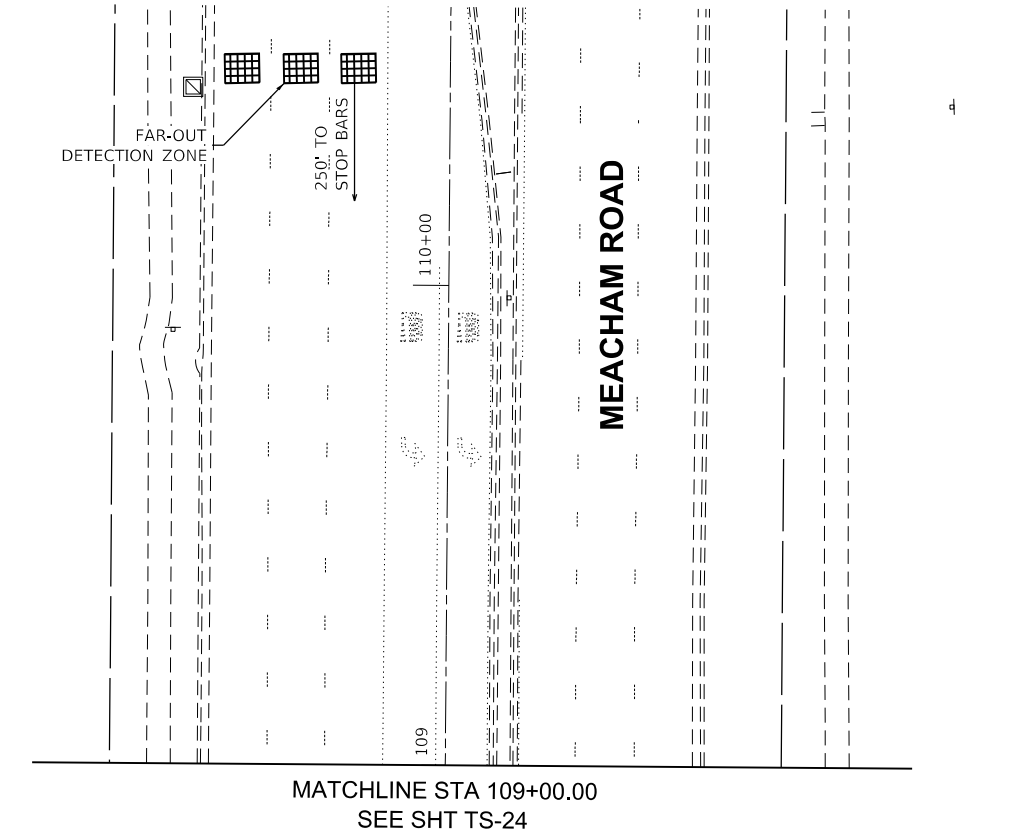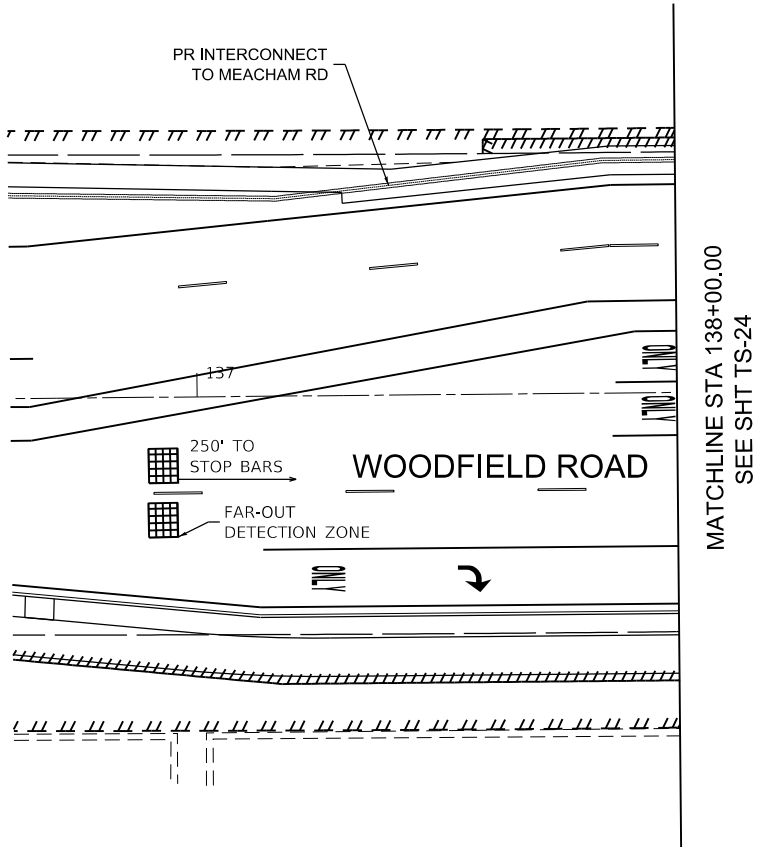


MODEL Default
FILE Name: \\ggedem\projects\2121304_CADD_01\CADD_Sheets\Woodfield-Sht-26_Meacham Rd_Prop Cable Plan.dgn


PROPOSED CONTROLLER SEQUENCE

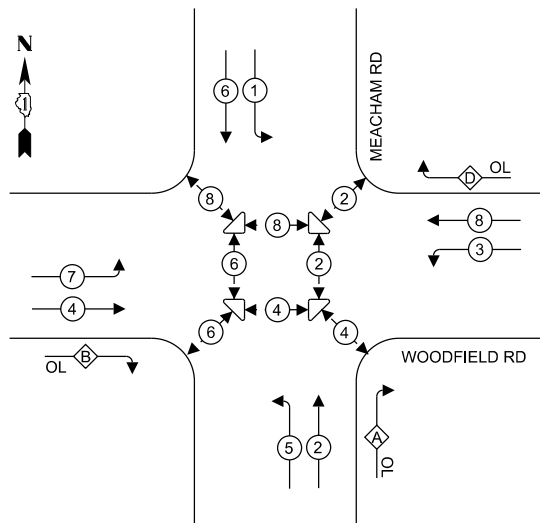

PROPOSED EMERGENCY VEHICLE
PREEMPTION SEQUENCE

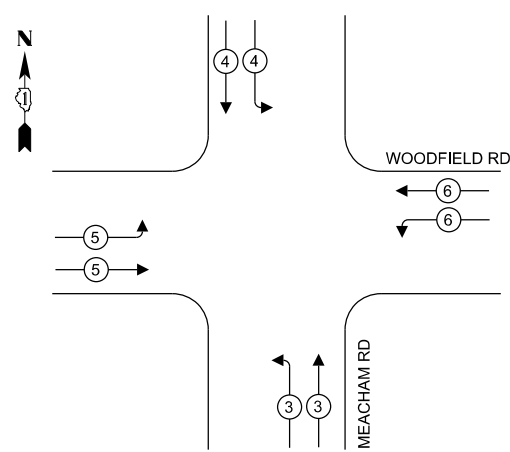

LEGEND:

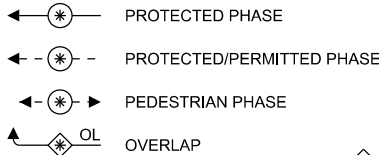

RIGHT TURN OVERLAP
PHASE DESIGNATION:

OVERLAP LETTER		PERMISSIVE PHASE		PROTECTED PHASE
A	=	2	+	3
B	=	4	+	5
D	=	8	+	1

NOTES

- ALL RED SIGNAL INDICATIONS SHALL HAVE A LENS COVER

ENERGY COSTS TO:

VILLAGE OF SCHAUMBURG

101 SCHAUMBURG COURT
SCHAUMBURG, IL 60193

ENERGY SUPPLY: CONTACT: ARTURO SALDIVAR

PHONE:

COMPANY: COMED

ACCOUNT NUMBER: XXXXX-XXXXX

TOWER ACCOUNT NUMBER: 0245068017

SINGH
SINGH & ASSOCIATES, INC.
CONSULTING ENGINEERS

USER NAME	= ggedemr
PLOT SCALE	= 2,0000 ' / in.
PLOT DATE	= 9/5/2025


DESIGNED	-	EEC	REVISED	-
DRAWN	-	EEC	REVISED	-
CHECKED	-	MG	REVISED	-
DATE	-	09/05/2025	REVISED	-

STATE OF ILLINOIS
DEPARTMENT OF TRANSPORTATION

CABLE PLAN, PHASE DESIGNATION DIAGRAM, AND
EMERGENCY VEHICLE PREEMPTION SEQUENCE
WOODFIELD ROAD AT MEACHAM ROAD

SCALE: NTS SHEET 1 OF 1 SHEETS STA. TO STA.


F.A.U. RTE.	SECTION	COUNTY	TOTAL SHEETS	SHEET NO.
3073	20-00134-00-R5	COOK	166	111
CONTRACT NO. 61L43				
ILLINOIS FED. AID PROJECT				

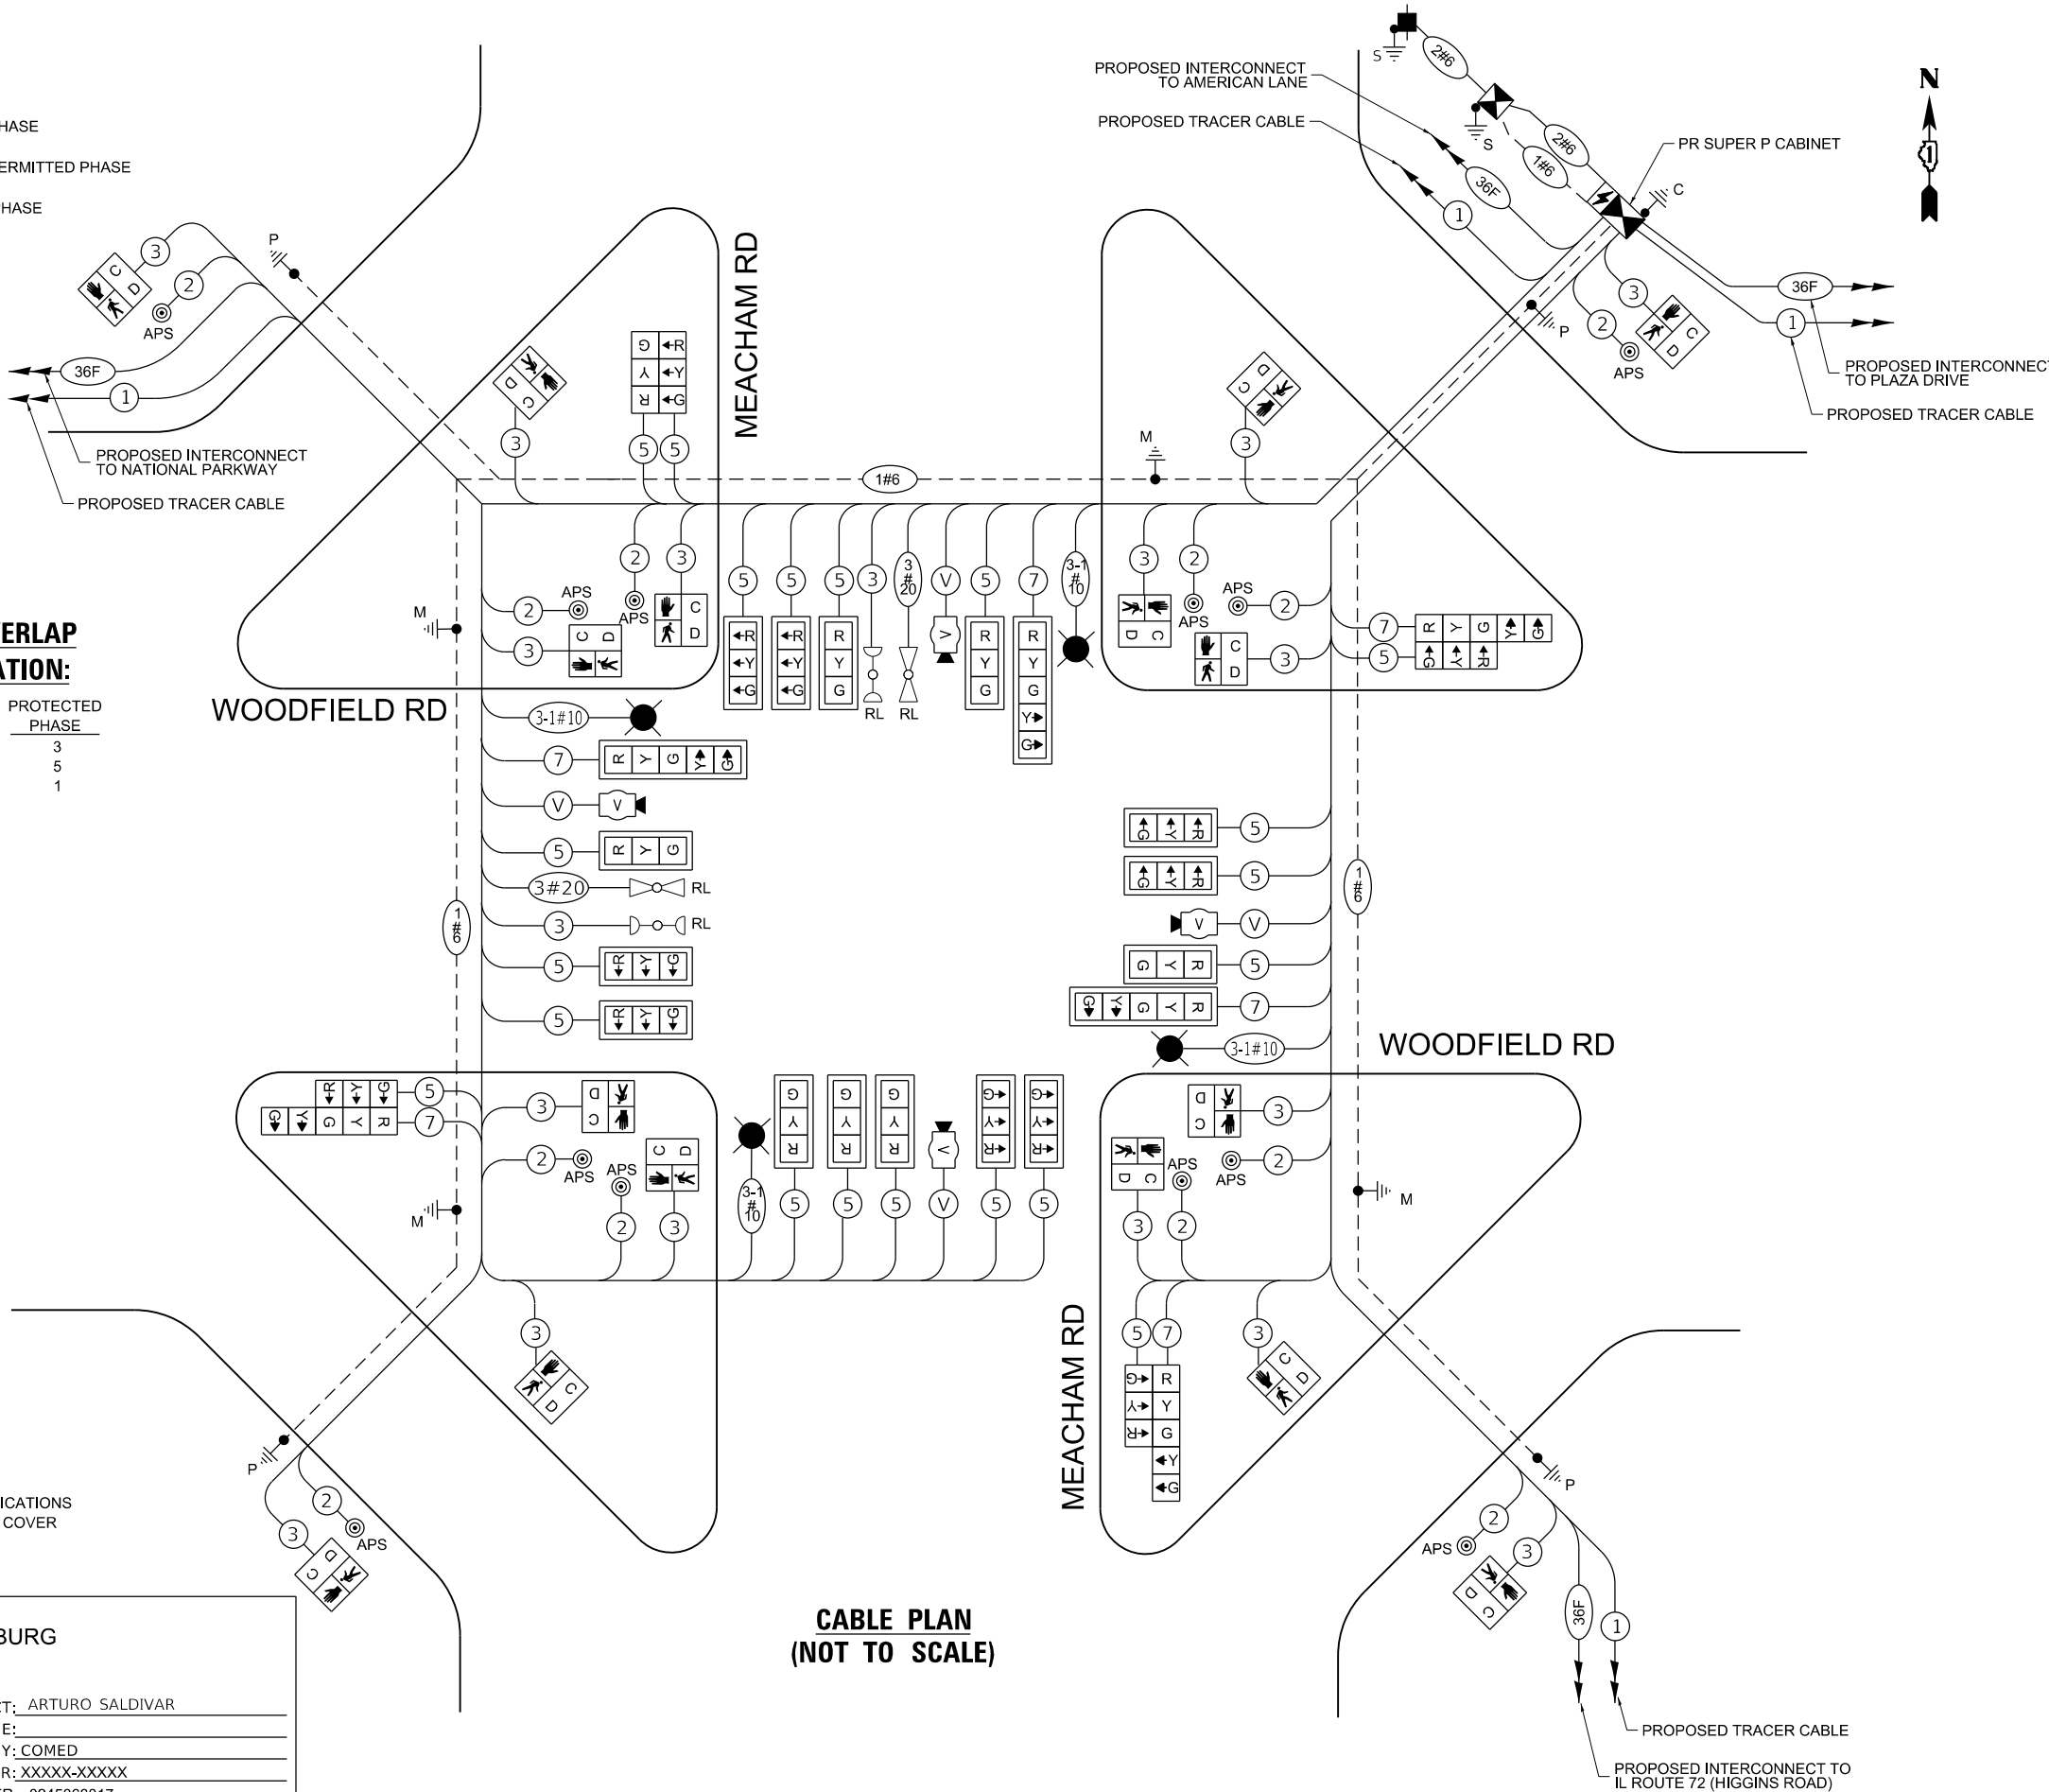


MODEL Default
FILE Name: W011\Project\2121304_CADD_01\CADD_Sheets\Woodfield-Sht-27_Meacham Rd_S00.dgn

SIGN PANEL – TYPE 1 OR TYPE 2


ALL DIMENSIONS ARE IN INCHES UNLESS NOTED OTHERWISE

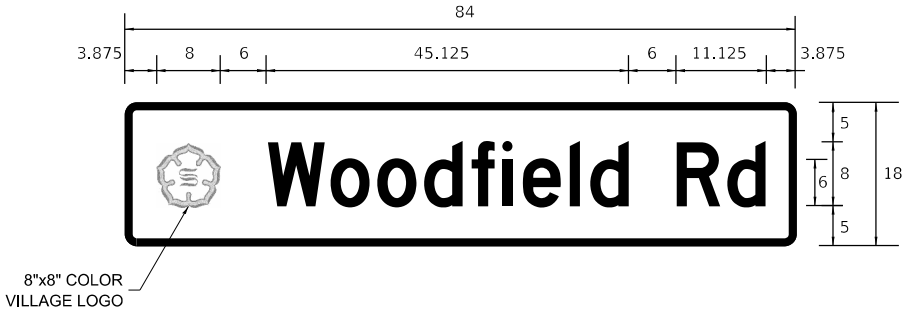


DESIGN SERIES	AREA (SQ FT)	QTY. REQUIRED
D	10.5	2

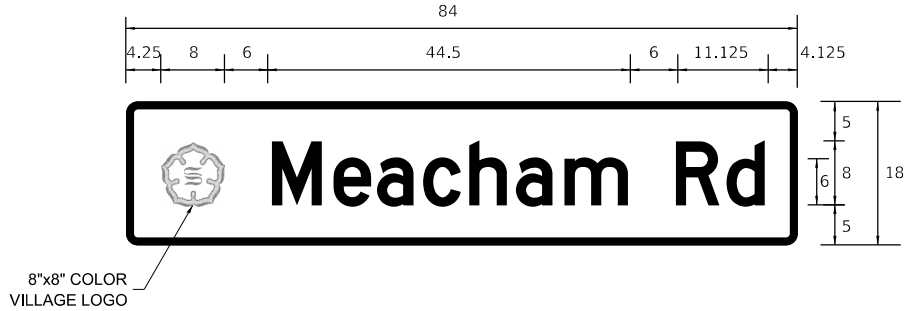

DESIGN SERIES	AREA (SQ FT)	QTY. REQUIRED
D	10.5	2

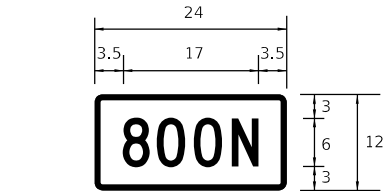

DESIGN SERIES	AREA (SQ FT)	QTY. REQUIRED
C	2	2

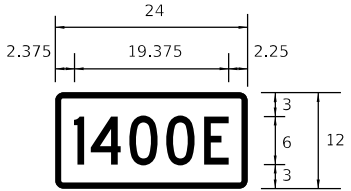

DESIGN SERIES	AREA (SQ FT)	QTY. REQUIRED
C	2	2

NOTE: FOR ADDITIONAL DESIGN AND INSTALLATION INFORMATION PLEASE SEE DISTRICT ONE MAST ARM MOUNTED STREET NAME SIGNS DETAIL.

SCHEDULE OF QUANTITIES

ITEM DESCRIPTION	UNITS	TOTAL QTY
SIGN PANEL - TYPE 1	SQ FT	68
SIGN PANEL - TYPE 2	SQ FT	42
UNDERGROUND CONDUIT, GALVANIZED STEEL, 2" DIA.	FOOT	99
UNDERGROUND CONDUIT, GALVANIZED STEEL, 4" DIA.	FOOT	641
HANDHOLE	EACH	5
DOUBLE HANDHOLE	EACH	3
ELECTRIC CABLE IN CONDUIT, 600V (XLP-TYPE USE) 3-1/C NO. 10	FOOT	881
* PAINT NEW COMBINATION MAST ARM AND POLE, 40 FOOT AND OVER	EACH	4
ELECTRIC CABLE IN CONDUIT, SIGNAL NO. 14 2C	FOOT	2,466
ELECTRIC CABLE IN CONDUIT, SIGNAL NO. 14 3C	FOOT	3,735
ELECTRIC CABLE IN CONDUIT, SIGNAL NO. 14 5C	FOOT	4,769
ELECTRIC CABLE IN CONDUIT, SIGNAL NO. 14 7C	FOOT	1,690
ELECTRIC CABLE IN CONDUIT, SERVICE, NO. 6 2 C	FOOT	65
ELECTRIC CABLE IN CONDUIT, EQUIPMENT GROUNDING CONDUCTOR, NO. 6 1C	FOOT	1,718
STEEL COMBINATION MAST ARM ASSEMBLY AND POLE 50 FT.	EACH	1
STEEL COMBINATION MAST ARM ASSEMBLY AND POLE 56 FT.	EACH	1
STEEL COMBINATION MAST ARM ASSEMBLY AND POLE 64 FT.	EACH	1
STEEL COMBINATION MAST ARM ASSEMBLY AND POLE 68 FT.	EACH	1
CONCRETE FOUNDATION, TYPE A	FOOT	4
CONCRETE FOUNDATION, TYPE C	FOOT	4
CONCRETE FOUNDATION, TYPE E 36-INCH DIAMETER	FOOT	15
CONCRETE FOUNDATION, TYPE E 42-INCH DIAMETER	FOOT	67
SIGNAL HEAD, LED, 1-FACE, 3-SECTION, MAST-ARM MOUNTED	EACH	10
SIGNAL HEAD, LED, 1-FACE, 3-SECTION, BRACKET MOUNTED	EACH	12
SIGNAL HEAD, LED, 1-FACE, 5-SECTION, BRACKET MOUNTED	EACH	3
SIGNAL HEAD, LED, 1-FACE, 5-SECTION, MAST-ARM MOUNTED	EACH	3
PEDESTRIAN SIGNAL HEAD, LED, 1-FACE, BRACKET MOUNTED WITH COUNTDOWN TIMER	EACH	16
TRAFFIC SIGNAL BACKPLATE, LOUVERED, FORMED PLASTIC	EACH	15
TEMPORARY TRAFFIC SIGNAL INSTALLATION	EACH	1
* RELOCATE EXISTING EMERGENCY VEHICLE PRIORITY SYSTEM, DETECTOR UNIT	EACH	2
* RELOCATE EXISTING EMERGENCY VEHICLE PRIORITY SYSTEM, PHASING UNIT	EACH	1
REMOVE ELECTRIC CABLE FROM CONDUIT	FOOT	8,500
REMOVE EXISTING TRAFFIC SIGNAL EQUIPMENT	EACH	1
REMOVE EXISTING HANDHOLE	EACH	12
REMOVE EXISTING DOUBLE HANDHOLE	EACH	3
REMOVE EXISTING CONCRETE FOUNDATION	EACH	9
* EMERGENCY VEHICLE PRIORITY SYSTEM LINE SENSOR CABLE, NO. 20 3/C	FOOT	375
SERVICE INSTALLATION, GROUND MOUNTED, METERED	EACH	1
PEDESTRIAN SIGNAL POST, 10 FT.	EACH	1
* PAINT NEW PEDESTRIAN PUSH-BUTTON POST	EACH	4
FULL-ACTUATED CONTROLLER AND TYPE SUPER P CABINET (SPECIAL)	EACH	1
UNINTERRUPTABLE POWER SUPPLY, SPECIAL	EACH	1
ACCESSIBLE PEDESTRIAN SIGNALS	EACH	12
CONCRETE FOUNDATION, TYPE A 12-INCH DIAMETER	FOOT	16
LED SIGNAL FACE, LENS COVER	EACH	26
VIDEO VEHICLE DETECTION SYSTEM	EACH	1
TEMPORARY TRAFFIC SIGNAL TIMING	EACH	1

* 100% COST TO THE VILLAGE OF SCHAUMBURG



USER NAME = ggedemer	DESIGNED - EEC	REVISED -
DRAWN - EEC	REVISED -	
PLOT SCALE = 2.0000 ' / in.	CHECKED - MG	REVISED -
PLOT DATE = 9/5/2025	DATE - 09/05/2025	REVISED -

STATE OF ILLINOIS
DEPARTMENT OF TRANSPORTATION

MAST ARM MOUNTED STREET NAME SIGNS
AND SCHEDULE OF QUANTITIES
WOODFIELD ROAD AT MEACHAM ROAD

SCALE: SHEET OF SHEETS STA. TO STA.

F.A.U. RTE.	SECTION	COUNTY	TOTAL SHEETS	SHEET NO.
3073	20-00134-00-R5	COOK	166	112
CONTRACT NO. 61L43				
ILLINOIS FED. AID PROJECT				

MODEL Default
FILE Name: W01\Project\2121304_CADD_01\CADD_Sheets\Woodfield-Sht-28_Temp Interconnect Plan.dgn




USER NAME	= ggedemer	DESIGNED -	EEC	REVISED -	
		DRAWN -	EEC	REVISED -	
PLOT SCALE	= 100,0000 ' / in.	CHECKED -	MG	REVISED -	
PLOT DATE	= 9/5/2025	DATE	= 09/05/2025	REVISED -	

STATE OF ILLINOIS
DEPARTMENT OF TRANSPORTATION

TEMPORARY INTERCONNECT PLAN
WOODFIELD RD - FROM NATIONAL PKWY TO MEACHAM RD

SCALE: 1"=50' SHEET 1 OF 1 SHEETS STA. TO STA.

F.A.U. RTE.	SECTION	COUNTY	TOTAL SHEETS	SHEET NO.
3073	20-00134-00-R5	COOK	166	113
CONTRACT NO. 61L43				
ILLINOIS FED. AID PROJECT				

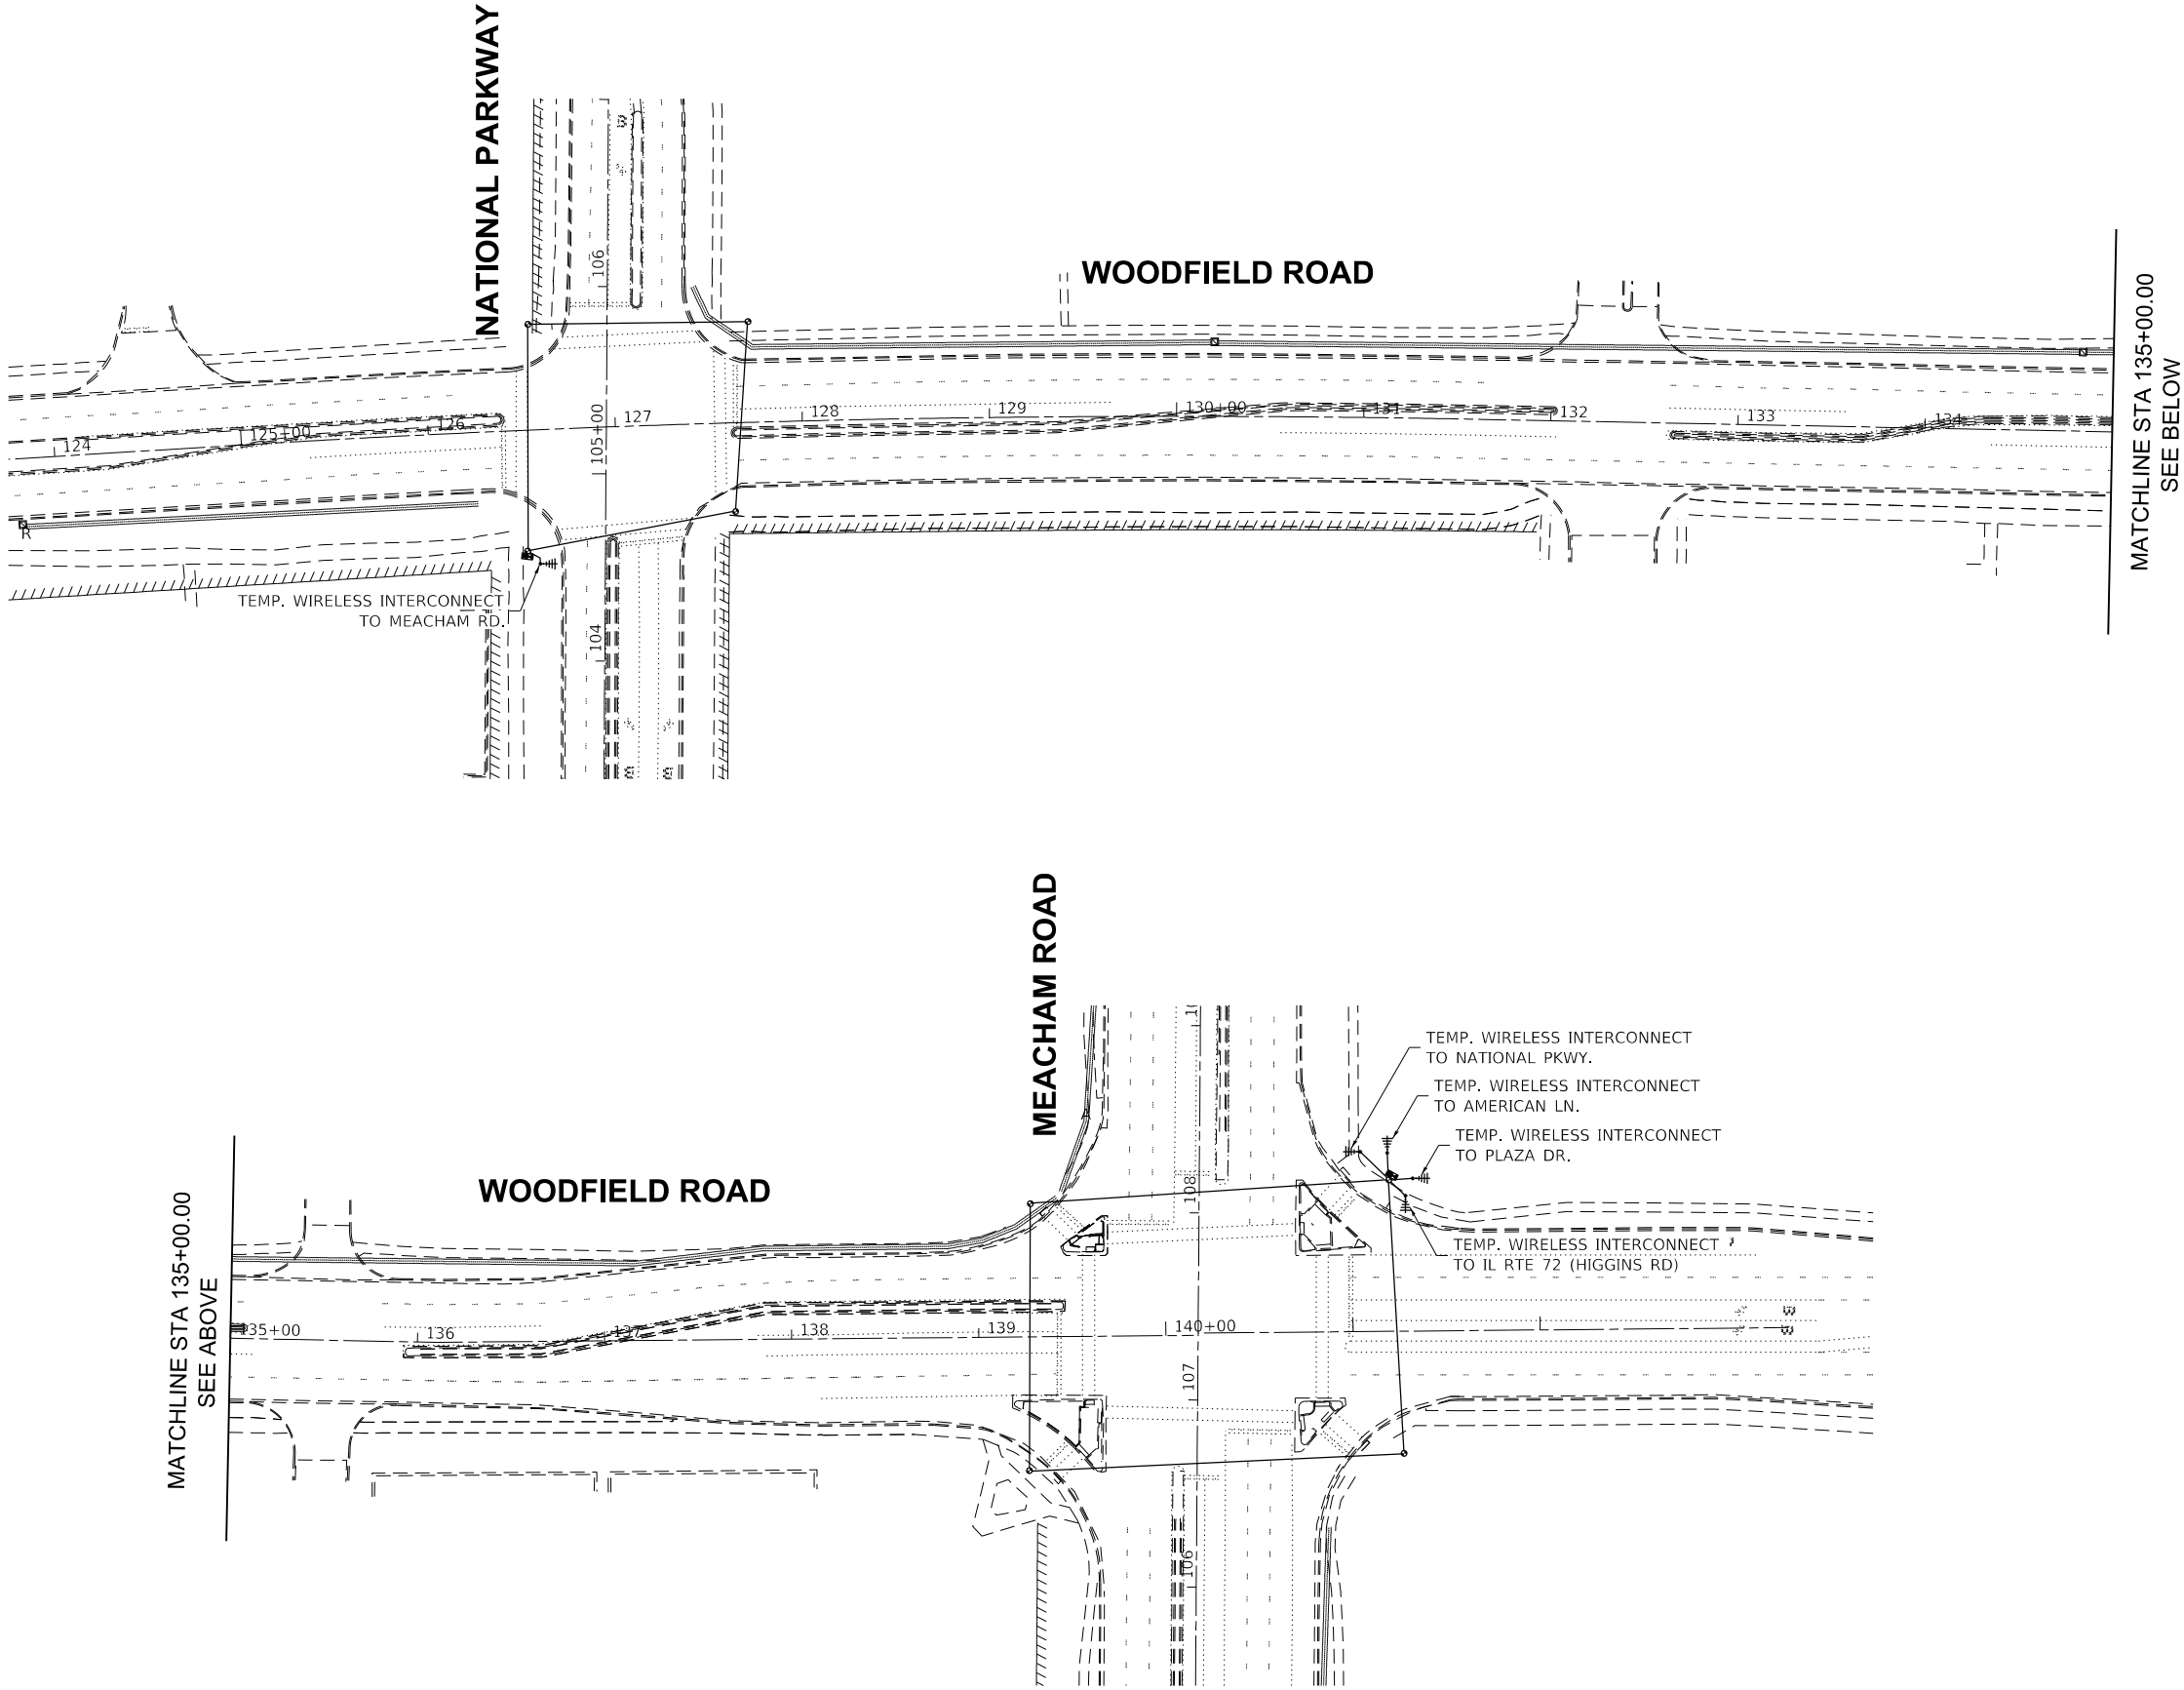

MODEL Default
FILE Name: W0119project\2121304_CADD_01\CADD_Sheets\Woodfield-Sht-29_Temp Interconnect Schematics.dgn




USER NAME	= ggedemer	DESIGNED -	EEC	REVISED -	
		DRAWN -	EEC	REVISED -	
PLOT SCALE	= 2,0000 ' / in.	CHECKED -	MG	REVISED -	
PLOT DATE	= 9/5/2025	DATE -	09/05/2025	REVISED -	

STATE OF ILLINOIS
DEPARTMENT OF TRANSPORTATION

TEMPORARY INTERCONNECT SCHEMATICS
WOODFIELD ROAD – NATIONAL PARKWAY TO I-290 EAST FRONTAGE ROAD

SCALE: SHEET OF SHEETS STA. TO STA.

F.A.U. RTE.	SECTION	COUNTY	TOTAL SHEETS	SHEET NO.
3073	20-00134-00-R5	COOK	166	114
CONTRACT NO. 61L43				
ILLINOIS		FED. AID PROJECT		

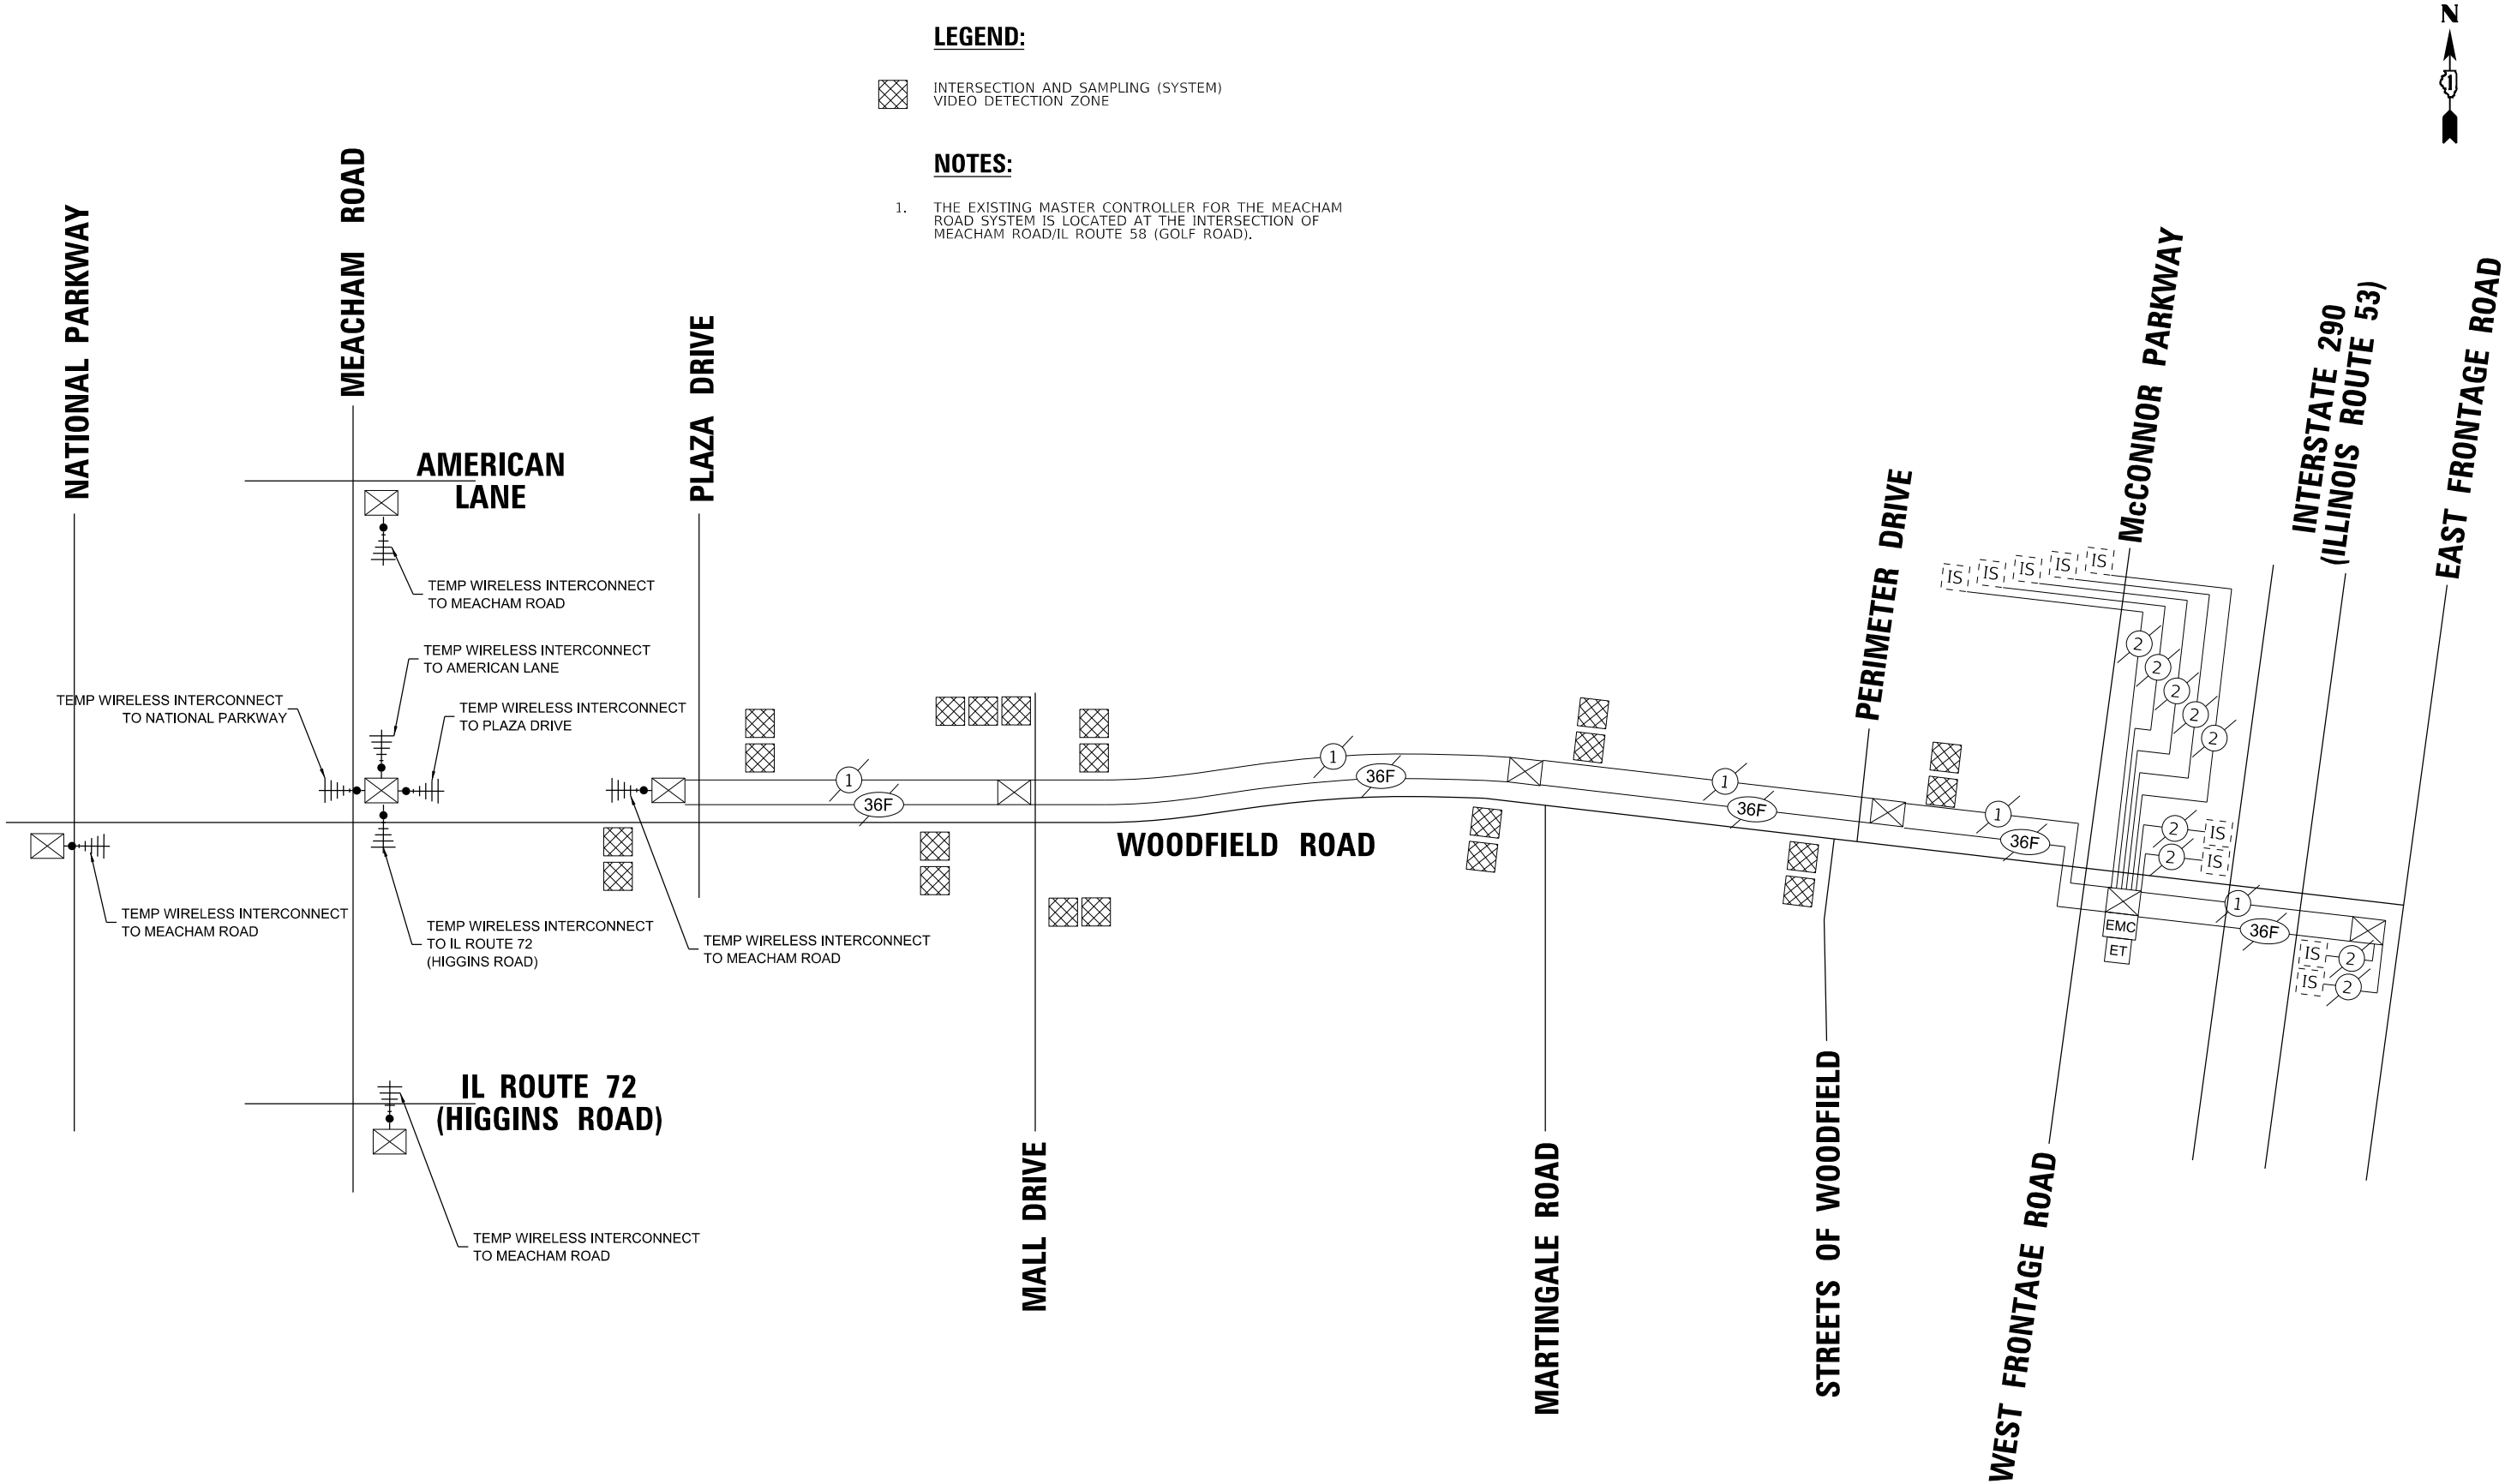

MODEL Default
FILE Name: W011Project2121304_CADD_01CADD_SheetsWoodfield-Sht-30_Prop Interconnect Plan.dgn






USER NAME = ggedemer	DESIGNED - EEC	REVISED -
	DRAWN - EEC	REVISED -
PLOT SCALE = 100,0000 ' / in.	CHECKED - MG	REVISED -
PLOT DATE = 9/5/2025	DATE - 09/05/2025	REVISED -

STATE OF ILLINOIS
DEPARTMENT OF TRANSPORTATION

PROPOSED INTERCONNECT PLAN
WOODFIELD RD - NATIONAL PKWY TO MEACHAM RD

SCALE: 1"=50' SHEET 1 OF 1 SHEETS STA. TO STA.

F.A.U. RTE.	SECTION	COUNTY	TOTAL SHEETS	SHEET NO.
3073	20-00134-00-R5	COOK	166	115
CONTRACT NO. 61L43				
ILLINOIS FED. AID PROJECT				

 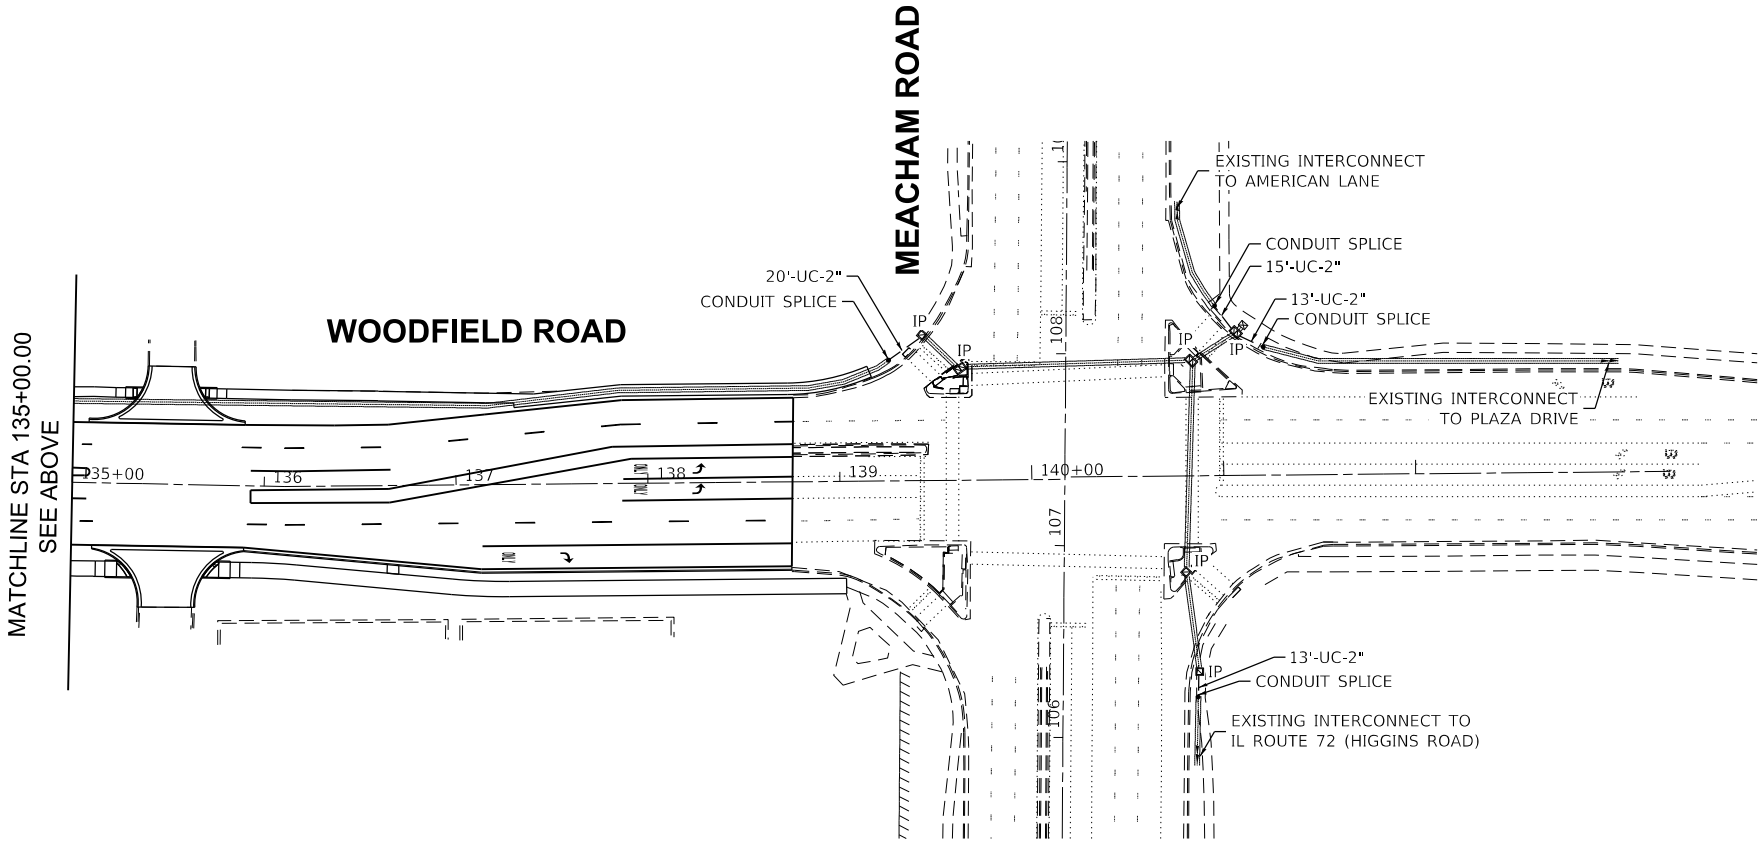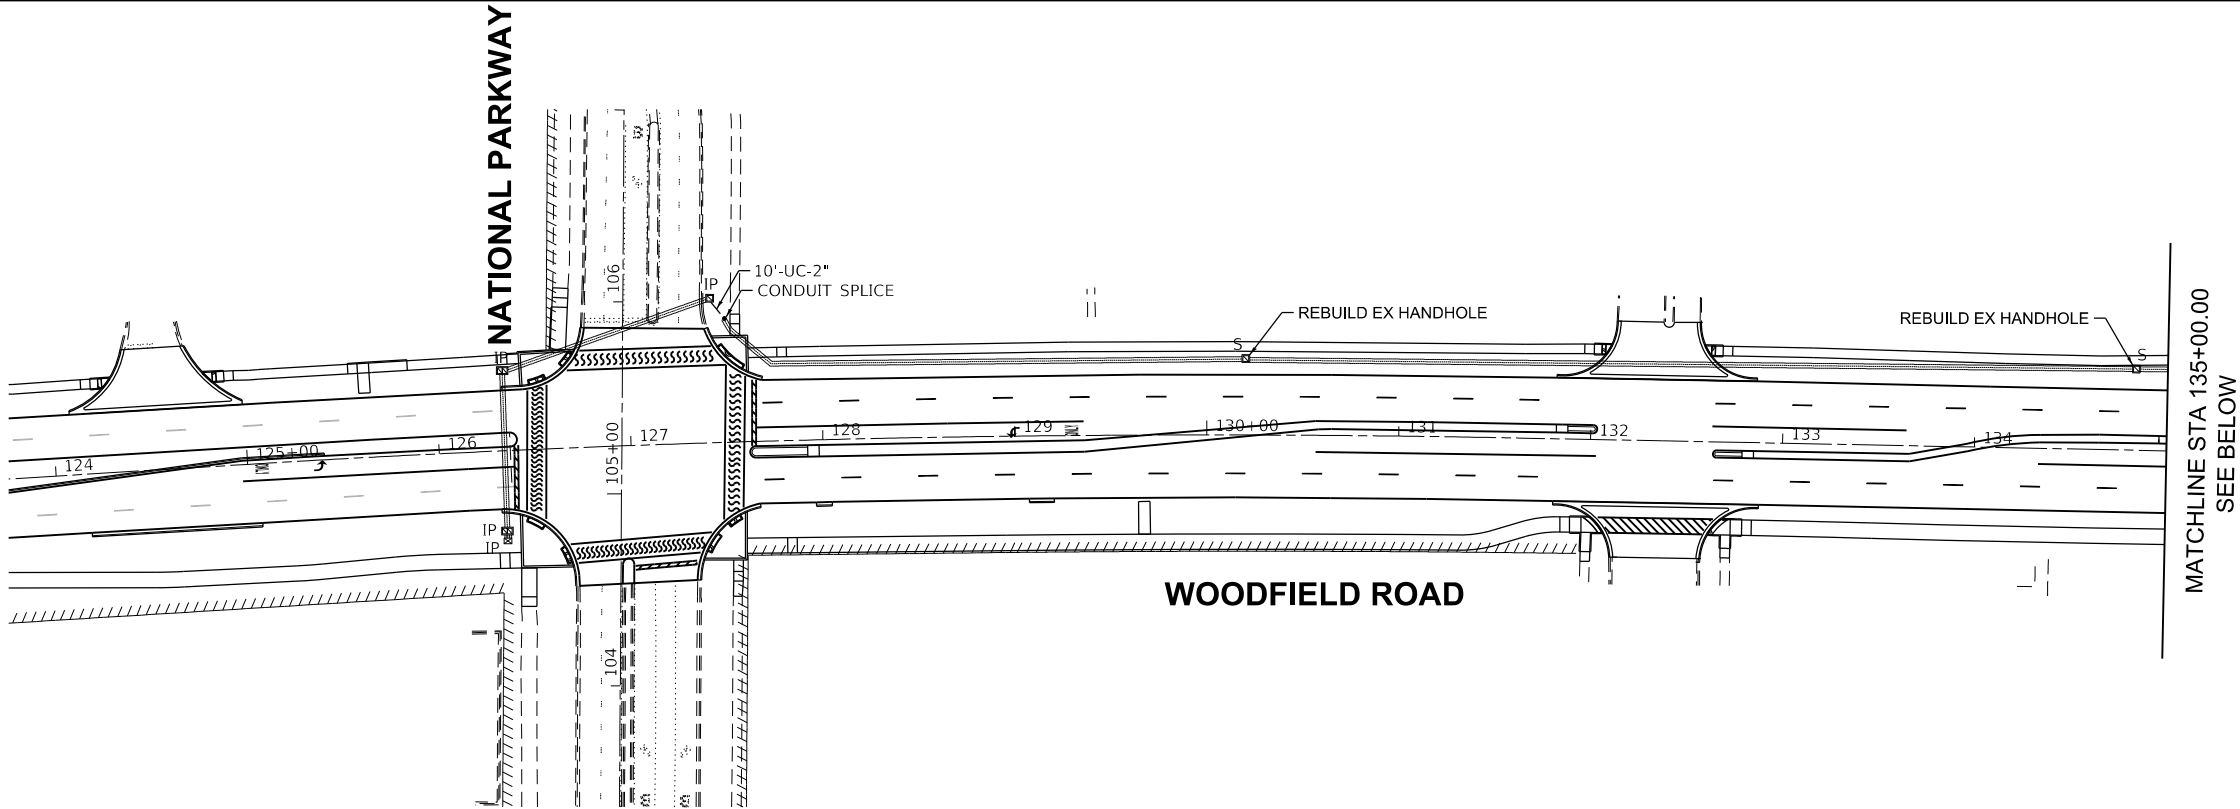

MODEL Default
FILE Name: W011\Project\2121304_CADD_01\CADD_Sheets\Woodfield-Sht-31_Prop Interconnect Schematic.dgn



USER NAME	= ggedemer
PLOT SCALE	= 2,0000 ' / in.
PLOT DATE	= 9/5/2025

DESIGNED -	EEC
DRAWN -	EEC
CHECKED -	MG
DATE -	09/05/2025

REVISED -	
REVISED -	
REVISED -	
REVISED -	

STATE OF ILLINOIS
DEPARTMENT OF TRANSPORTATION

PROPOSED INTERCONNECT SCHEMATICS
WOODFIELD ROAD – NATIONAL PARKWAY TO I-290 EAST FRONTAGE ROAD

SCALE:	SHEET	OF	SHEETS	STA.	TO	STA.
--------	-------	----	--------	------	----	------

F.A.U. RTE.	SECTION	COUNTY	TOTAL SHEETS	SHEET NO.
3073	20-00134-00-R5	COOK	166	116
CONTRACT NO. 61L43				
ILLINOIS		FED. AID PROJECT		

LEGEND:

INTERSECTION AND SAMPLING (SYSTEM)
VIDEO DETECTION ZONE



NOTES:

1. THE EXISTING MASTER CONTROLLER FOR THE MEACHAM ROAD SYSTEM IS LOCATED AT THE INTERSECTION OF MEACHAM ROAD/IL ROUTE 58 (GOLF ROAD).

SCHEDULE OF QUANTITIES

ITEM DESCRIPTION	UNITS	TOTAL QTY
UNDERGROUND CONDUIT, GALVANIZED STEEL, 2" DIA.	FOOT	71
MAINTENANCE OF EXISTING TRAFFIC SIGNAL INSTALLATION	EACH	4
TRANSCIVER - FIBER OPTIC	EACH	5
ELECTRICAL CABLE IN CONDUIT, TRACER, NO. 14 1C	FOOT	5,050
REMOVE ELECTRIC CABLE FROM CONDUIT	FOOT	5,150
REBUILD EXISTING HANDHOLE	EACH	2
ROD AND CLEAN EXISTING CONDUIT	FOOT	4,400
CONDUIT SPLICE	EACH	5
FIBER OPTIC CABLE IN CONDUIT, NO. 62.5/125 MM12F SM24F	FOOT	5,050
REMOVE FIBER OPTIC CABLE FROM CONDUIT	FOOT	5,150
RE-OPTIMIZE TRAFFIC SIGNAL SYSTEM LEVEL 1	EACH	2

 * NOMINAL QAUNTITY TO BE USED AS NEEDED AND AS APPROVED BY THE ENGINEER

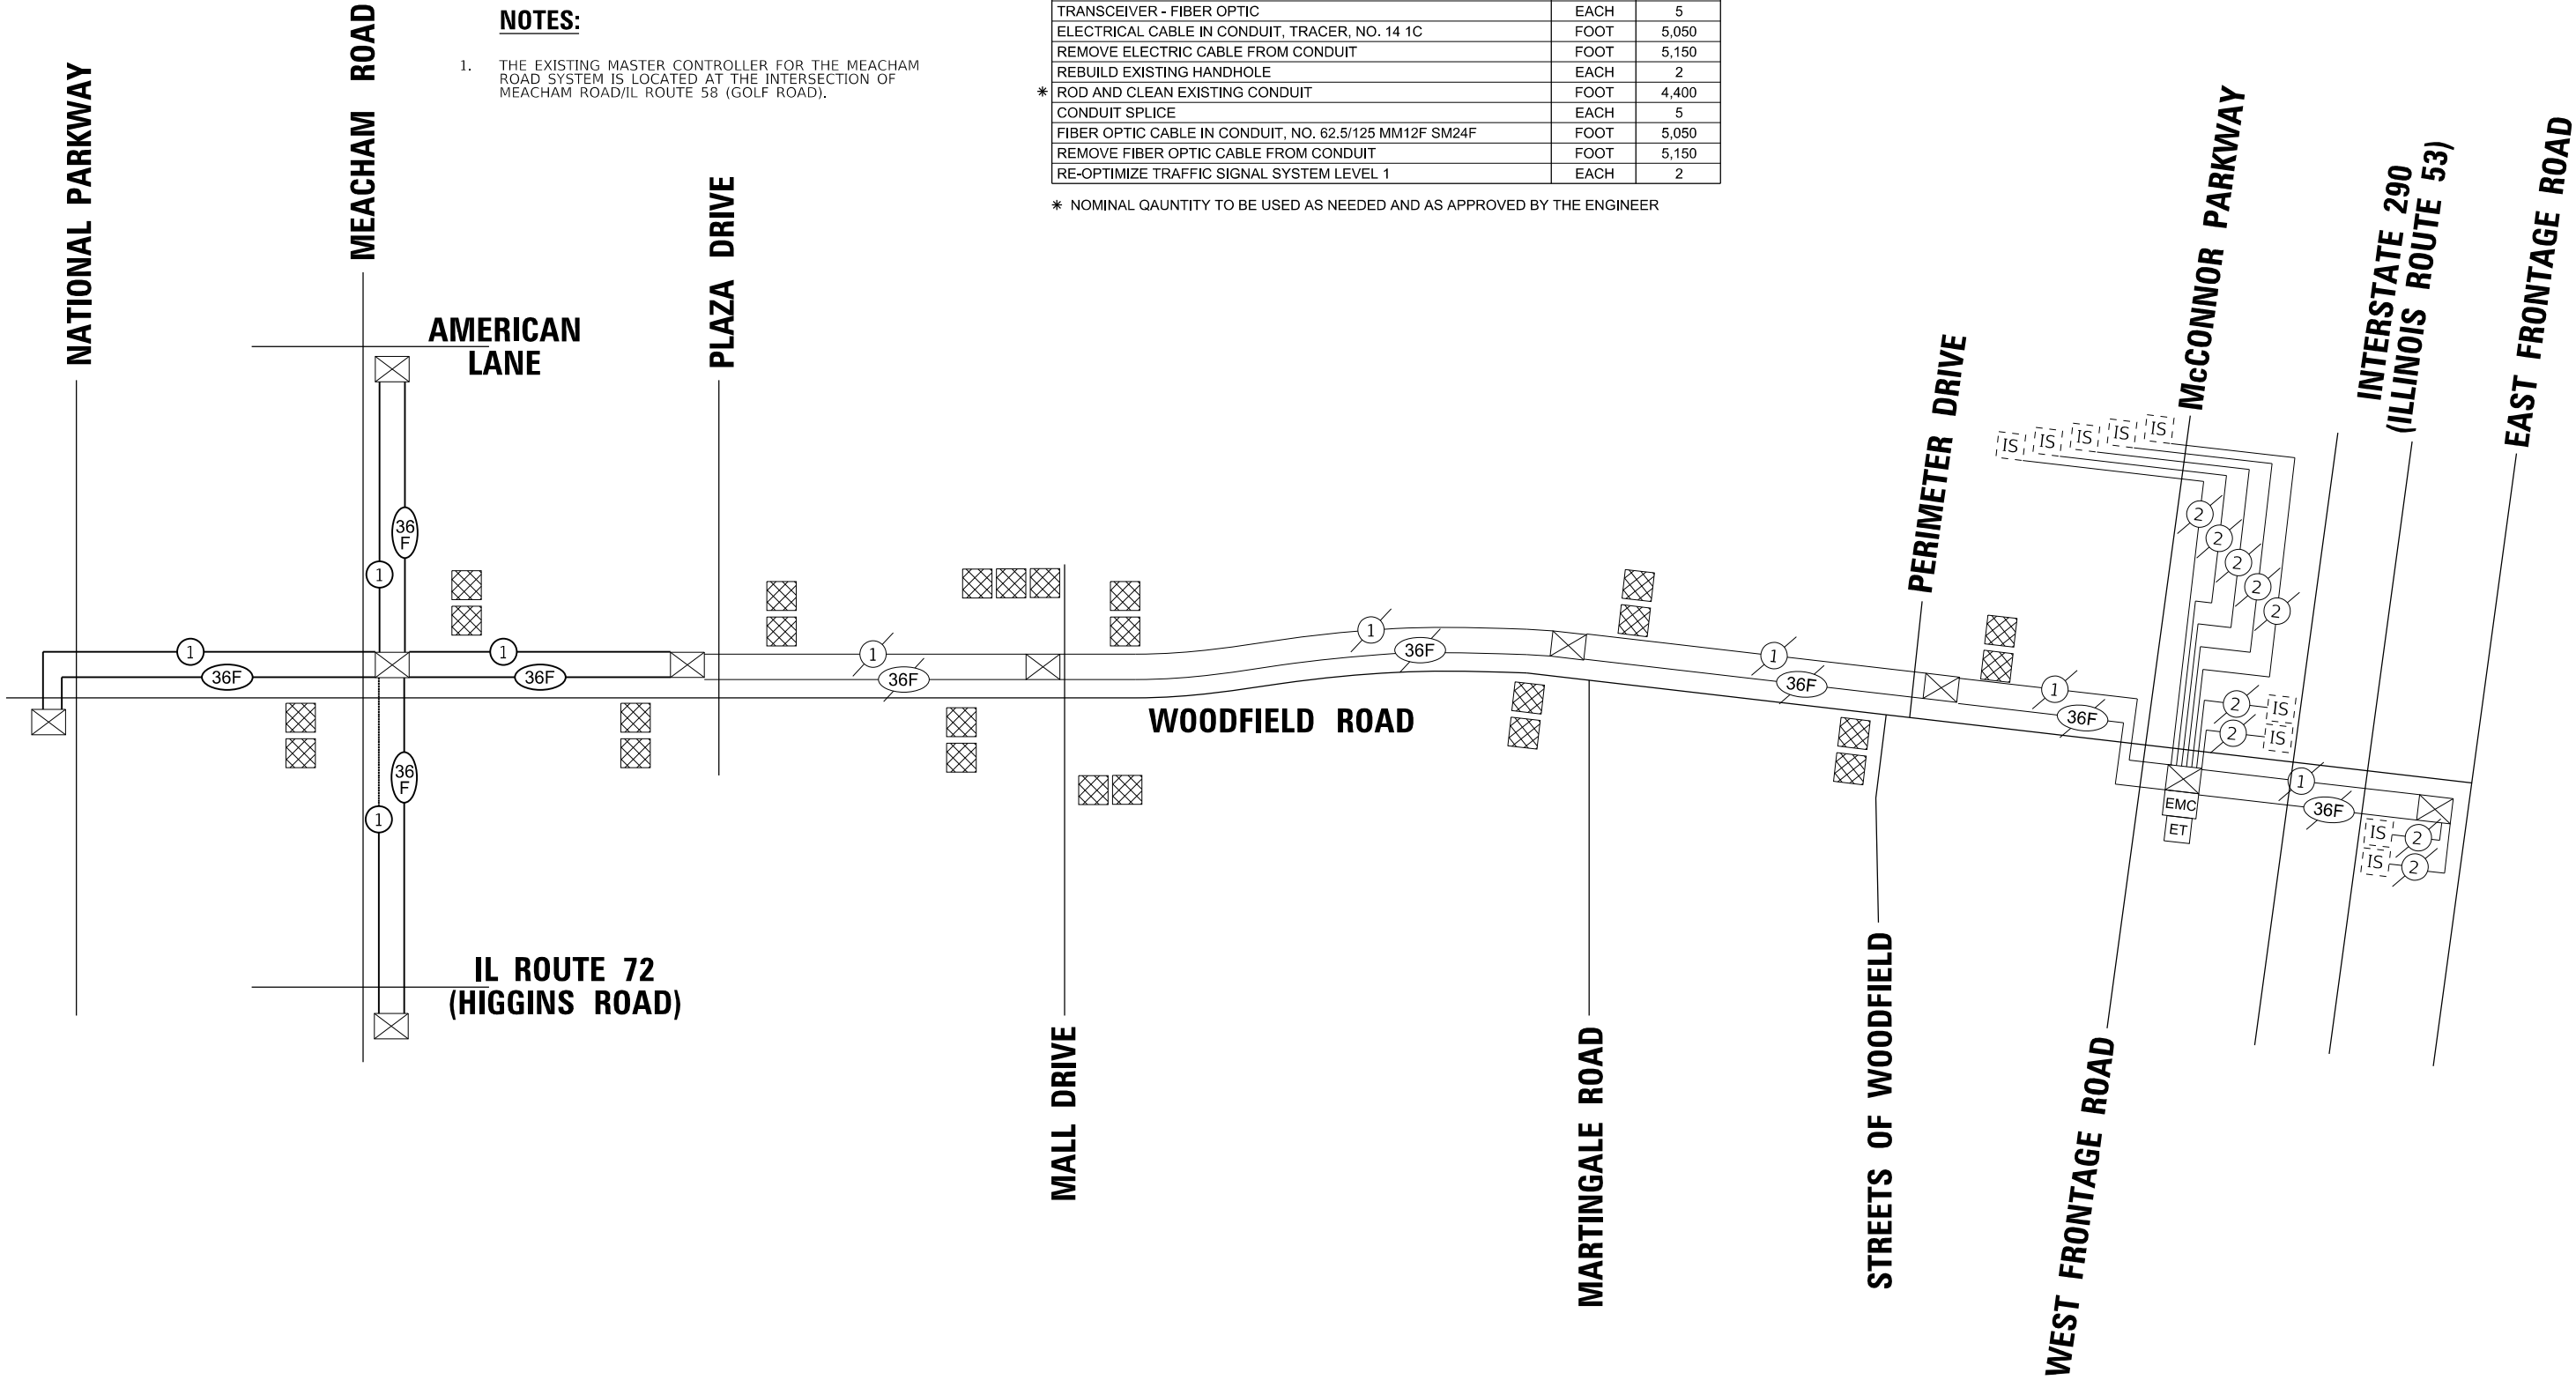

LIGHTING GENERAL NOTES

1.

PRIOR TO THE INSTALLATION OF THE NEW UNIT DUCTS, CABLES, CONDUITS, JUNCTION BOXES LIGHT STANDARD FOUNDATIONS AND APPURTENANCES, THE CONTRACTOR SHALL DETERMINE THE EXACT LOCATION OF EXISTING CONDUITS, CABLES AND UNDERGROUND. UTILITIES. THE CONTRACTOR SHALL CALL J.U.L.I.E. (800-893-0123) TO LOCATE AND MARK/STAKE ALL APPLICABLE UNDERGROUND UTILITIES.
2.

THE CONTRACTOR SHALL VERIFY ALL INFORMATION SHOWN ON THE CONTRACT PLANS AND REFERENCE DRAWINGS WHICH WOULD AFFECT HIS/HER WORK UNDER THIS CONTRACT OR THE OPERATION OF THE EXISTING ROADWAY LIGHTING IF ANY.
3.

ALL NEW UNIT DUCTS, CONDUITS CABLES, JUNCTION BOXES AND APPURTENANCES ARE DIAGRAMMATICALLY SHOWN THEREFORE THE ACTUAL LOCATION IN THE FIELD MUST MEET THE APPROVAL OF THE ENGINEER.
4.

CONDUIT AND UNIT DUCT MUST BE POSITIONED IN THE FIELD TO AVOID CONFLICT WITH TREES, BUSHES DRAINS, OTHER UTILITIES AND LANDSCAPING. THE PREFERRED LOCATION OF UNIT DUCT IS 12 INCHES OFF THE THE CABLE TRENCH SHALL BE BACKFILLED AND FIRMLY COMPACTED BEFORE ANY LIGHT STANDARD IS ERECTED. BACK OF CURB AND IN NO CASE SHALL IT BE CLOSER THAN 12 INCHES. LOCATIONS OF CONDUIT/UNIT DUCT GREATER THAN 12 INCHES BASED ON FIELD CONDITIONS WILL BE APPROVED BY RESIDENT ENGINEER PRIOR TO INSTALLATION.
5.

ALL UNDERGROUND CONDUIT AND DUCT SHALL BE INSTALLED NOT LESS THAN 2'-9" BELOW FINISHED GRADE OR 45" BELOW THE TOP OF PAVEMENT UNLESS INDICATED OTHERWISE.
6.

NO MATERIAL OR EQUIPMENT SHALL BE DELIVERED TO THE JOB SITE WITHOUT PRIOR INSPECTION AND APPROVAL OF THE ENGINEER. ANY MATERIAL AND EQUIPMENT NOT APPROVED BY THE ENGINEER MUST BE REMOVED FROM THE JOB SITE AT THE CONTRACTOR'S EXPENSE.
7.

THE ELECTRICAL MATERIAL MUST BE NEW AND OF THE TYPES AND KINDS APPROVED BY THE FOLLOWING ORGANIZATIONS.

a.

NATIONAL ELECTRICAL MANUFACTURERS ASSOCIATION (NEMA)

b.

INSTITUTE OF ELECTRICAL AND ELECTRONICS ENGINEERS (IEEE)

c.

INSTITUTE OF ELECTRICAL AND ELECTRONICS ENGINEERS (IEEE)

d.

ILLUMINATING ENGINEERS SOCIETY OF NORTH AMERICA (IES)

e.

AMERICAN ASSOCIATION OF STATE HIGHWAY AND TRANSPORTATION OFFICIALS (AASHTO)

f.

U.S. DEPARTMENT OF TRANSPORTATION (USDOT)

g.

UNDERWRITERS LABORATORIES (UL)

h.

AMERICAN NATIONAL STANDARD INSTITUTE (ANSI)

i.

INSULATED POWER AND CABLE ENGINEERS ASSOCIATION (IPCEA)

8.

ALL ELECTRICAL SYSTEMS, EQUIPMENT AND APPURTENANCES SHALL BE PROPERLY GROUNDED IN STRICT CONFORMANCE WITH THE NATIONAL ELECTRICAL CODE, EVEN THOUGH EVERY DETAIL OF REQUIREMENTS IS NOT SPECIFIED OR SHOWN. GROUNDING CONDUCTORS SHALL BE CONTINUOUS.

9.

IT SHALL BE THE CONTRACTOR RESPONSIBILITY TO MARK THE PROPOSED LOCATION OF ALL LIGHT POLES FOR EXAMINATION AND CONFIRMATION BY THE RESIDENT ENGINEER.

10.

THE CONTRACTOR SHALL BE RESPONSIBLE FOR THE ESTABLISHMENT OF THE FINISHED GRADE. THE RESIDENT ENGINEER MAY ASSIST THE CONTRACTOR, AS APPLICABLE. BUT THE RESPONSIBILITY FOR COORDINATING THE FINISHED GRADE ELEVATION WITH THE TOP OF FOUNDATIONS, HEIGHTS AND THE LIGHT SHALL REMAIN WITH THE CONTRACTOR.

11.

HELIX FOUNDATION SHALL BE PER DETAIL PROVIDED PER SHEET 64. BOLT CIRCLE, SHAFT DIAMETER, SHAFT LENGTH AND BASEPLATE DIMENSIONS SHALL BE PER TABLE PROVIDED AND POLE MOUNTING HEIGHT.

12.

FOR ALL CONCRETE FOUNDATIONS A MINIMUM OF 2 SLEEVES SHALL BE PROVIDED REGARDLESS OF WHAT IS BEING INSTALLED, THE SLEEVES SHALL BE SEALED AND CAPPED TO PREVENT MOISTURE OR CONTAMINANTS, MATERIAL AND LABOR WILL NOT BE PAID FOR SEPARATELY BUT WILL BE INCLUDED IN THE PAY ITEM FOR LIGHT POLE FOUNDATIONS.

13.

TO MAINTAIN STRUCTURAL INTEGRITY OF ALUMINUM POLES WITH MAST ARMS, THEY SHALL NOT BE ERECTED AND LEFT TO STAND WITHOUT LUMINARIES. NOTE THAT THE CONTRACTOR SHALL NOT BE PAID FOR POLES UNTIL LUMINARIES ARE INSTALLED.

14.

THE CABLE TRENCH SHALL BE BACKFILLED AND FIRMLY COMPACTED BEFORE ANY LIGHT STANDARD IS ERECTED.

15.

THE INSTALLATION OF BURIED WARNING TAPE SHALL BE INSPECTED AND APPROVED BY THE ENGINEER PRIOR TO INSTALLATION.

16.

NO UNDERGROUND SPLICING OF CABLE IS PERMITTED.

17.

SEE CIVIL DEMOLITION PLAN FOR REMOVED LIGHT POLES WITHIN THE PROJECT'S SCOPE (ALL EXISTING LIGHTING UNIT TO BE REMOVED ALONG WITH ASSOCIATED CABLE AND CONDUIT IN ITS ENTIRETY BACK TO CONTROLLER SOURCE.

18.

ALL ELECTRICAL EQUIPMENT SHALL BE LISTED AND LABELED.

19.

ALL CIRCUIT WIRES SHALL BE LABELED WITH CIRCUIT IDENTIFICATION AND ALL LIGHTING CIRCUITS SHALL BE WIRED IN ACCORDANCE WITH THE PLANS. DEVIATIONS WILL NOT BE PERMITTED WITHOUT PRIOR APPROVAL OF THE ENGINEER.
- LIGHTING GENERAL NOTES (CONT.)
20.

ALL CIRCUITS SHALL BE TESTED PER SPECIFICATIONS.

21.

FOR COMED SERVICE FOR TEMPORARY CONTROLLER CONTACT COMED AT LEAST 60 DAYS BEFORE THE DATE REQUIRED FOR COMED WORK TO START.

22.

REMOVE EXISTING LIGHTING UNIT INCLUDING ALL ASSOCIATED CABLE IN ITS ENTIRETY BACK TO CONTROLLER AFTER TEMPORARY LIGHTING SYSTEM IS INSTALLED, TESTED AND FULLY OPERATIONAL. SALVAGE LIGHTING UNIT INCLUDING LIGHT POLE, MAST ARM AND LUMINAIRE AND RETURN TO OWNER AT LOCATION AS DIRECTED BY OWNER.

23.

SELECT HELIX BOLT CIRCLE, SHAFT DIAMETER SHAFT LENGTH AND BASEPLATE DIMENSIONS SO LUMEC POLE ATR106V-38-BAB30.5(2)-CAP3-GF11-VD-BE6TX FITS PROPERLY AND PLUMB SECURE INSTALLATION. FOR 38' POLE USE HELIX FOUNDATION WITH 15" BOLT CIRCLE, 8-5/8 " DIAMETER, AND BASEPLATE 15"x15"x1-1/4", F OR HELIX FOUNDATION SEE LIGHTING DETAILS SHEET.

24.

ANY DAMAGE TO PAVEMENT, SIDEWALK, CURB, OR ANY OTHER PORTION OF THE ROADWAY NOT SPECIFICALLY TO BE REMOVED AND REPLACED BY THE CONTRACTOR SHALL BE REPAIRED OR REPLACED BY CONTRACTOR AT NO ADDITIONAL COST AND REPLACEMENT SHALL MEET THE APPROVAL OF THE ENGINEER.
- SCHEDULE OF QUANTITIES
- | CODED PAY
ITEM NO | ITEM | UNIT | TOTAL
QUANTITY |
|----------------------|---|--------|-------------------|
| 80400200 | ELECTRIC UTILITY SERVICE CONNECTION | L SUM | 1 |
| 81028240 | UNDERGROUND CONDUIT, GALVANIZED STEEL, 4' DIA. FOOT | FOOT | 1275 |
| 81400200 | HEAVY DUTY HANDHOLE | EACH | 4 |
| 81800230 | AERIAL CABLE, 2-1/C NO. 6 WITH MESSENGER WIRE | FOOT | 7300 |
| 81800300 | AERIAL CABLE, 3-1/C NO 2 WITH MESSENGER WIRE | EACH | 120 |
| 83600356 | LIGHT POLE FOUNDATION, METAL, 15" BOLT CIRCLE, 8-5/8" X 6' | EACH | 44 |
| 84100110 | REMOVAL OF TEMPORARY LIGHTING UNIT | EACH | 44 |
| 84200500 | REMOVAL OF LIGHTING UNIT, SALVAGE | EACH | 34 |
| 84200804 | REMOVAL OF POLE FOUNDATION | EACH | 34 |
| 89502300 | REMOVE ELECTRIC CABLE FROM CONDUIT | FOOT | 7300 |
| X1400238 | LUMINAIRE, LED, SPECIAL | EACH | 44 |
| X1400346 | MAST ARM, STEEL, 8 FOOT | EACH | 44 |
| X8040104 | TEMPORARY ELECTRIC SERVICE INSTALLATION | EACH | 1 |
| X8163577 | UNIT DUCT, 600V, 4-1C NO. 8, 3-1/C NO. 2 AND 1/C NO. 2 GROUND, (XLP-TYPE USE), 1 1/2" DIA. POLYETHYLENE | FOOT | 7774 |
| X8180064 | AERIAL CABLE REMOVAL | FOOT | 7420 |
| X8211001 | TEMPORARY LUMINAIRE, LED, ROADWAY, OUTPUT DESIGNATION B | EACH | 44 |
| X8250060 | TEMPORARY LIGHTING CONTROLLER | EACH | 1 |
| X8250507 | MAINTAIN EXISTING LIGHTING CONTROLLER | EACH | 1 |
| X8300001 | LIGHT POLE (SPECIAL) | EACH | 44 |
| X8302140 | WOOD POLE, 40 FT, CLASS 4 | EACH | 45 |
| X8380075 | BREAKAWAY DEVICE, TRANSFORMER BASE (SPECIAL) | EACH | 44 |
| Z0033020 | LUMINAIRE SAFETY CABLE ASSEMBLY | EACH | 44 |
| Z0033028 | MAINTENANCE OF LIGHTING SYSTEM | CAL MO | 18 |
- MODEL: Default
FILE: 20200503-19011001\CCADD\CCAD Sheets\190114-sh-light-gennotes.dgn
-  **Globetrotters®**
Engineering Corporation

USER NAME = kelly.jirikox	DESIGNED - RH	REVISED -
	DRAWN - CW	REVISED -
PLOT SCALE = 20,0000 ' / in.	CHECKED - TDM	REVISED -
PLOT DATE = 9/19/2025	DATE - 01/11/2025	REVISED -


STATE OF ILLINOIS
DEPARTMENT OF TRANSPORTATION

WOODFIELD ROAD

LIGHTING DETAILS – GENERAL NOTES AND SCHEDULE OF QUANTITIES

SCALE: N/A SHEET 1 OF 1 SHEETS STA. N/A TO STA. N/A

F.A.U RTE.	SECTION	COUNTY	TOTAL SHEETS	SHEET NO.
3073	20-00134-00-RS	COOK	166	117
CONTRACT NO. 61L43				
ILLINOIS		FED. AID PROJECT		

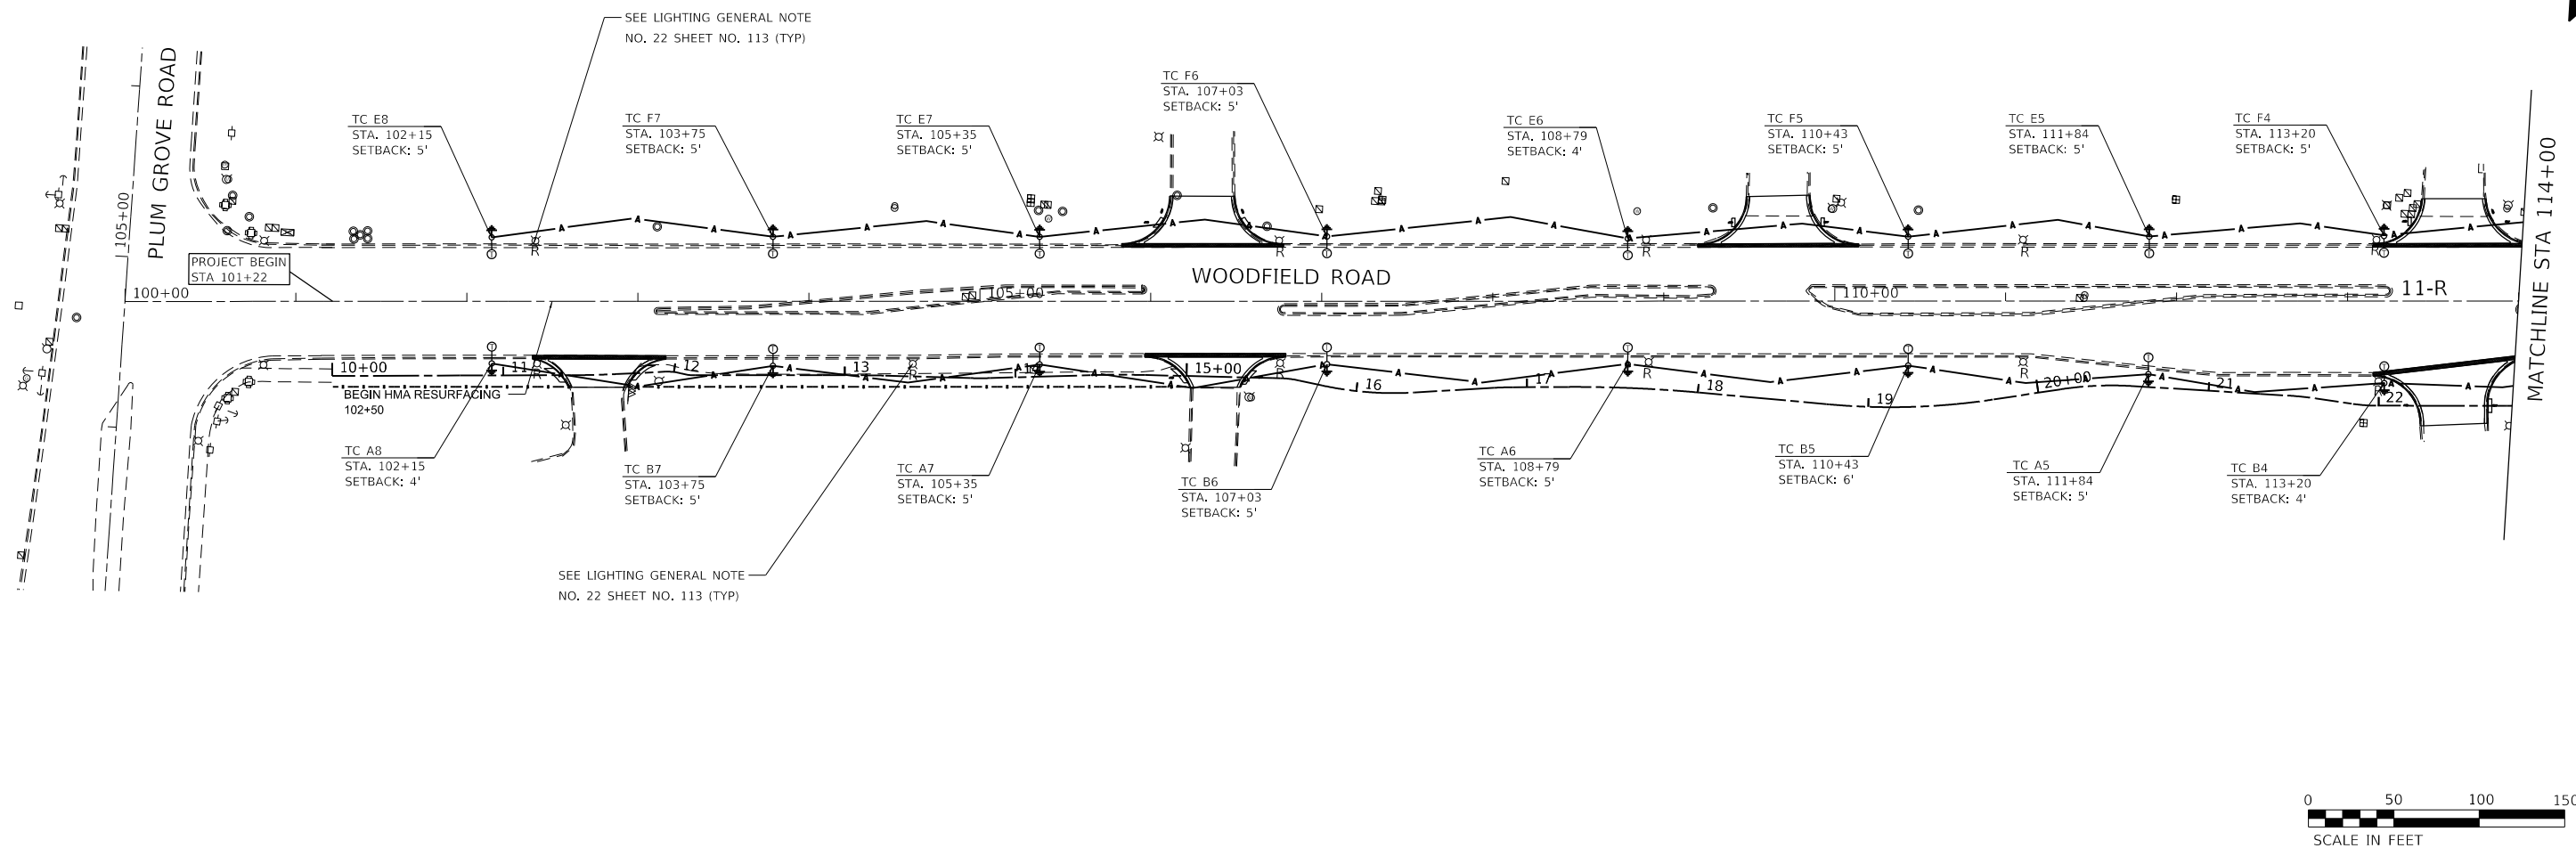

TEMPORARY LIGHTING NOTES:

1. SETBACK IS MEASURED FROM EXISTING FACE OF CURB TO THE CENTER OF THE LIGHT POLE FOR THE TEMPORARY LIGHTING UNITS.
2. THE CONTRACTOR SHALL REMOVE ALL TEMPORARY LIGHTING EQUIPMENT AFTER ALL PERMANENT PROPOSED LIGHTING IS INSTALLED AND OPERATIONAL.
3. ALL TEMPORARY LIGHTING EQUIPMENT REMOVAL WILL BE INCLUDED IN THE COST OF THE PAY ITEM FOR THE TEMPORARY WOOD POLE.
4. ALL MATERIALS, EQUIPMENT, AND LABOR NEEDED TO INSTALL AND CONNECT THE SERVICE FROM THE COMED UTILITY TRANSFORMER TO THE TEMPORARY LIGHTING CONTROLLED CABINET, SHALL BE PART OF THE PAY ITEM NO. 80400100 "ELECTRIC SERVICE INSTALLATION" THAT SHALL INCLUDE METER SOCKET, CABLE AND OTHER NEEDED MATERIAL. ALL CONNECTIONS SPLICING AND WIRING TO THE TEMPORARY LIGHTING CONTROLLER IS INCLUDED UNDER SAME PAY ITEM.
5. THE ELECTRIC SERVICE SHALL BE 240/120V SINGLE PHASE 3 WIRE SYSTEM. EACH LIGHTING UNIT SHALL BE CONTROLLED BY A PHOTOCCELL.
6. THE CONTRACTOR SHALL SPlice AERIAL CABLE AT THE LIGHT POLE USING HEAT SHRINKABLE CAPS WITH THE FACTORY APPLIED WATERPROOF SEALANT OR AN APPROVED UL LISTED AERIAL TAP DEVICE.

TEMPORARY LIGHTING NOTES:


7. THE LAYOUT OF TEMPORARY POLE EQUIPMENT WILL VARY BASED ON FIELD CONDITIONS, UTILITY IMPACTS AND ELECTRIC SERVICE LOCATION AS COORDINATED WITH ELECTRIC UTILITY. THE CONTRACTOR SHALL SUBMIT A PLAN INDICATING THE SETTING OF TEMPORARY POLES, THE PLAN MUST BE APPROVED BY ENGINEER BEFORE ANY POLES ARE PLACED.
8. ALL AREAS DISTURBED UNDER THIS CONTRACT SHALL BE RESTORED TO THE ORIGINAL CONDITION OR BETTER TO THE SATISFACTION OF THE ENGINEER.
9. REMOVE ALL EXISTING LIGHT UNITS TAG"R" INCLUDING ALL ASSOCIATED CABLE IN ITS ENTIRETY BACK TO CONTROLLER AFTER TEMPORARY LIGHTING SYSTEM IS INSTALLED TESTED AND FULLY OPERATIONAL.
10. COST OF SPLICES AND MOUNTING HARDWARE SHALL BE INCLUDED IN THE UNIT PRICE FOR AERIAL CABLE.
11. TEMPORARY LIGHTING SHALL BE REMOVED ONCE THE PERMANENT LIGHTING IS INSTALLED AND OPERATIONAL. THE COST TO REMOVE AERIAL CABLE SHALL BE INCLUDED IN THE CONTRACT UNIT PRICE FOR REMOVE TEMPORARY LIGHT UNIT.
12. THE CONTRACTOR WILL BE RESPONSIBLE FOR THE MAINTENANCE OF ALL TEMPORARY LIGHTING WITHIN PROJECT LIMITS FOR THE DURATION OF THE PROJECT. ANY DAMAGE INCURRED DURING CONSTRUCTION SHALL BE PROMPTLY REPAIRED SO SERVICE IS NOT DISRUPTED. THE CONTRACTOR IS RESPONSIBLE FOR VERIFYING EXISTING CONDITIONS

TEMPORARY LIGHTING LEGEND:

- ↓ GROUND ROD 5/8" X 10'.
- 40' TEMPORARY LIGHTING UNIT WOOD POLE CLASS 4
8-FT MAST ARM, 26-FT MOUNTING HEIGHT.
- ▢ TEMPORARY LIGHTING CABINET "TC"
SINGLE DOOR, 100A, 120/240V SINGLE PHASE.
- ⊕ TEMPORARY ELECTRIC SERVICE TRANSFORMER
BY COMED ON PROPOSED UTILITY POLE.
- A — AERIAL CABLE, 2-1/C NO 6 WITH MESSENGER WIRE
(81800230).
- ⊗ R REMOVE EXISTING LIGHTING UNIT INCLUDING ALL ASSOCIATED
CABLE IN ITS ENTIRETY BACK TO CONTROLLER AFTER
TEMPORARY LIGHTING SYSTEM IS INSTALLED TESTED AND
FULLY OPERATIONAL. SALVAGE LIGHTING UNIT INCLUDING
LIGHT POLE, MAST ARM AND LUMINAIRE AND RETURN TO
OWNER AT LOCATION AS DIRECTED BY OWNER.
- TC PROVIDE A 100AMP 120/240V SINGLE PHASE 3W
TEMPORARY LIGHTING CONTROLLER AND COORDINATE
WITH COMED TO PROVIDE POWER TO TC.
- TEMPORARY WOOD POLE, 40 FT, CLASS 4

LOAD TABLE:

CIRCUIT	RED PHASE		CIRCUIT	RED PHASE	
	AMPS	WATTS		AMPS	WATTS
A	2.4	576	B	2.1	504
C	1.2	288	D	0.9	216
E	2.4	576	F	2.1	504
G	1.2	288	H	0.9	216
TOTAL LOAD ON TEMPORARY CONTROLLER=13.2 AMPS					

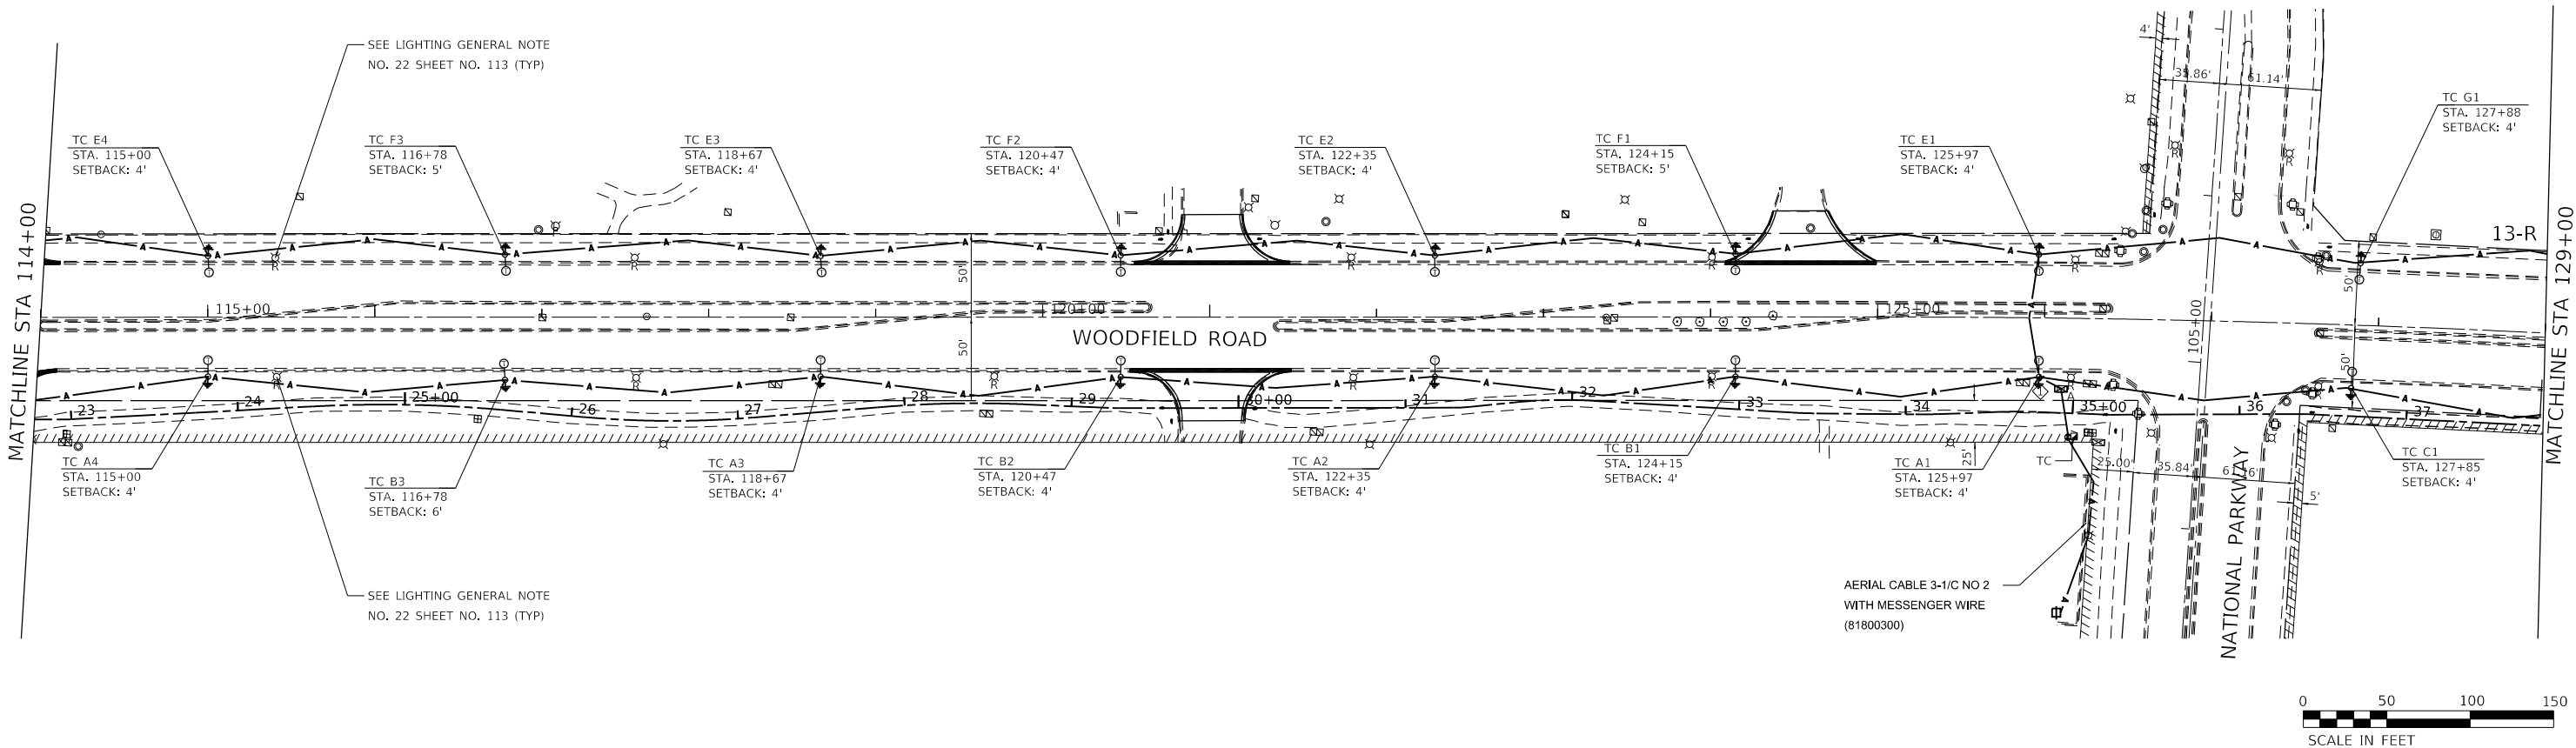

TEMPORARY LIGHTING NOTES:

1. SETBACK IS MEASURED FROM EXISTING FACE OF CURB TO THE CENTER OF THE LIGHT POLE FOR THE TEMPORARY LIGHTING UNITS.
2. THE CONTRACTOR SHALL REMOVE ALL TEMPORARY LIGHTING EQUIPMENT AFTER ALL PERMANENT PROPOSED LIGHTING IS INSTALLED AND OPERATIONAL.
3. ALL TEMPORARY LIGHTING EQUIPMENT REMOVAL WILL BE INCLUDED IN THE COST OF THE PAY ITEM FOR THE TEMPORARY WOOD POLE.
4. ALL MATERIALS, EQUIPMENT, AND LABOR NEEDED TO INSTALL AND CONNECT THE SERVICE FROM THE COMED UTILITY TRANSFORMER TO THE TEMPORARY LIGHTING CONTROLLED CABINET, SHALL BE PART OF THE PAY ITEM NO. 80400100 "ELECTRIC SERVICE INSTALLATION" THAT SHALL INCLUDE METER SOCKET, CABLE AND OTHER NEEDED MATERIAL. ALL CONNECTIONS SPLICING AND WIRING TO THE TEMPORARY LIGHTING CONTROLLER IS INCLUDED UNDER SAME PAY ITEM.
5. THE ELECTRIC SERVICE SHALL BE 240/120V SINGLE PHASE 3 WIRE SYSTEM. EACH LIGHTING UNIT SHALL BE CONTROLLED BY A PHOTOCELL.
6. THE CONTRACTOR SHALL SPLICE AERIAL CABLE AT THE LIGHT POLE USING HEAT SHRINKABLE CAPS WITH THE FACTORY APPLIED WATERPROOF SEALANT OR AN APPROVED UL LISTED AERIAL TAP DEVICE.

TEMPORARY LIGHTING NOTES:

7. THE LAYOUT OF TEMPORARY POLE EQUIPMENT WILL VARY BASED ON FIELD CONDITIONS, UTILITY IMPACTS AND ELECTRIC SERVICE LOCATION AS COORDINATED WITH ELECTRIC UTILITY. THE CONTRACTOR SHALL SUBMIT A PLAN INDICATING THE SETTING OF TEMPORARY POLES, THE PLAN MUST BE APPROVED BY ENGINEER BEFORE ANY POLES ARE PLACED.
8. ALL AREAS DISTURBED UNDER THIS CONTRACT SHALL BE RESTORED TO THE ORIGINAL CONDITION OR BETTER TO THE SATISFACTION OF THE ENGINEER.
9. REMOVE ALL EXISTING LIGHT UNITS TAG"R" INCLUDING ALL ASSOCIATED CABLE IN ITS ENTIRETY BACK TO CONTROLLER AFTER TEMPORARY LIGHTING SYSTEM IS INSTALLED TESTED AND FULLY OPERATIONAL.
10. COST OF SPLICES AND MOUNTING HARDWARE SHALL BE INCLUDED IN THE UNIT PRICE FOR AERIAL CABLE.
11. TEMPORARY LIGHTING SHALL BE REMOVED ONCE THE PERMANENT LIGHTING IS INSTALLED AND OPERATIONAL. THE COST TO REMOVE AERIAL CABLE SHALL BE INCLUDED IN THE CONTRACT UNIT PRICE FOR REMOVE TEMPORARY LIGHT UNIT.
12. THE CONTRACTOR WILL BE RESPONSIBLE FOR INSTALLING TEMPORARY 100A LIGHTING CONTROLLER COORDINATING WITH COMED TO POWER SAME. THE MAINTENANCE OF ALL TEMPORARY LIGHTING WITHIN PROJECT LIMITS FOR THE DURATION OF THE PROJECT. ANY DAMAGE INCURRED DURING CONSTRUCTION SHALL BE PROMPTLY REPAIRED SO SERVICE IS NOT DISRUPTED. THE CONTRACTOR IS RESPONSIBLE FOR VERIFYING EXISTING CONDITIONS.

TEMPORARY LIGHTING LEGEND:

- GROUND ROD 5/8" X 10'.
- USE 40' TEMPORARY LIGHTING UNIT WOOD POLE CLASS 4 8-FT MAST ARM, 26-FT MOUNTING HEIGHT.
- TEMPORARY LIGHTING CABINET "TC" SINGLE DOOR, 100A, 120/240V SINGLE PHASE.
- TEMPORARY ELECTRIC SERVICE TRANSFORMER BY COMED ON PROPOSED UTILITY POLE.
- AERIAL CABLE, 2-1/C NO 6 WITH MESSENGER WIRE (81800230).
- REMOVE EXISTING LIGHTING UNIT INCLUDING ALL ASSOCIATED CABLE IN ITS ENTIRETY BACK TO CONTROLLER AFTER TEMPORARY LIGHTING SYSTEM IS INSTALLED TESTED AND FULLY OPERATIONAL. SALVAGE LIGHTING UNIT INCLUDING LIGHT POLE ,MAST ARM AND LUMINAIRE AND RETURN TO OWNER AT LOCATION AS DIRECTED BY OWNER.
- TC PROVIDE A 100AMP 120/240V SINGLE PHASE 3W TEMPORARY LIGHTING CONTROLLER AND COORDINATE WITH COMED TO PROVIDE POWER TO TC.
- TEMPORARY WOOD POLE, 40 FT, CLASS 4

LOAD TABLE:

TEMPORARY LIGHTING CONTROLLER "TC" (240V)					
CIRCUIT	RED PHASE		CIRCUIT	RED PHASE	
	AMPS	WATTS		AMPS	WATTS
A	2.4	576	B	2.1	504
C	1.2	288	D	0.9	216
E	2.4	576	F	2.1	504
G	1.2	288	H	0.9	216
TOTAL LOAD ON TEMPORRAY CONTROLLER=13.2 AMPS					





USER NAME	= mohammed.ait	DESIGNED	- RH	REVISED	-
DRAWN	- CW	REVISION	-	REVISED	-
PLOT SCALE	= 100,0000 ' / in.	CHECKED	- TDM	REVISED	-
PLOT DATE	= 9/2/2025	DATE	- 01/11/2025	REVISED	-

STATE OF ILLINOIS
DEPARTMENT OF TRANSPORTATION

WOODFIELD ROAD
TEMPORARY LIGHTING DETAILS

SCALE: 1" = 50' SHEET 2 OF 3 SHEETS STA. 114+00 TO STA. 129+00

F.A.U RTE.	SECTION	COUNTY	TOTAL SHEETS	SHEET NO.
3073	20-00134-00-R5	COOK	166	119
CONTRACT NO. 61L43				
ILLINOIS FED. AID PROJECT				

 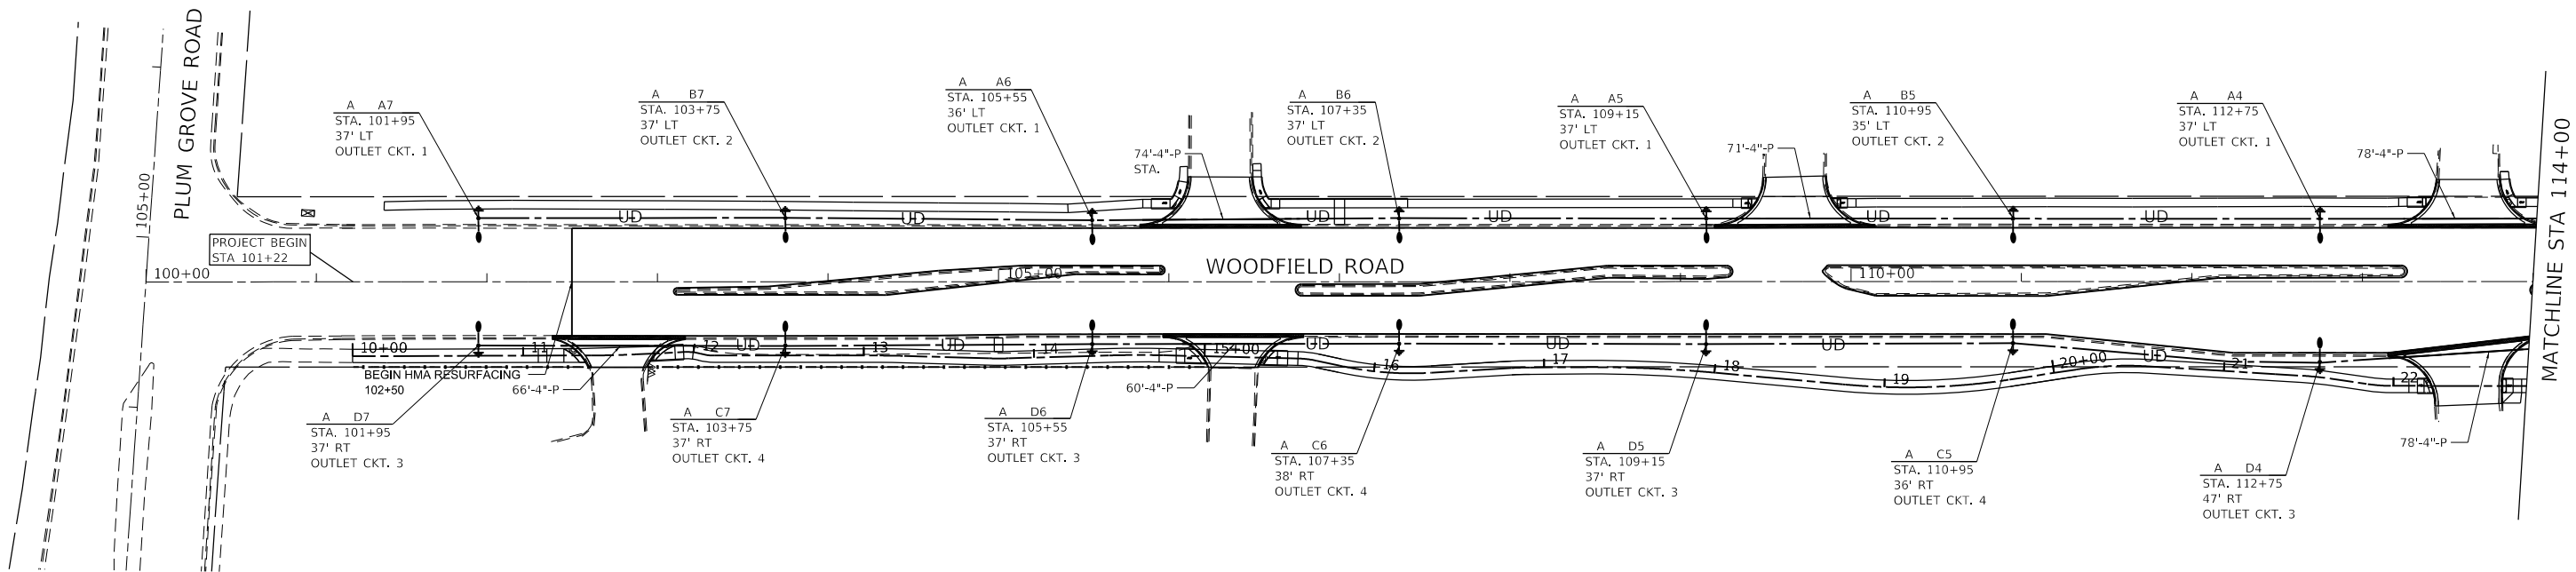

LIGHTING LEGEND:

-  PROPOSED LIGHTING UNIT WITH POLE BASE LOCATED 5-FT BEHIND PROPOSED EDGE OF PAVEMENT. 35-FT MOUNTING HEIGHT, MAST ARM LENGTH 3.5', 135W LED LUMINAIRE PHILIPS [TR20-009]-135W80LED4K-G3-LE2S-VOLT-DMG-BE6TX FESTOON OUTLET - 20AMP GFI/WEATHER PROOF COVER SEE DETAILS SHEET.
-  EXISTING LIGHTING CONTROLLER CABINET 120/240V SINGLE PHASE 3W 225AMP TO BE USED FOR PROPOSED LIGHTING FOR CIRCUITS A, B, C, D, E, AND F. USE EXISTING 2P BREAKERS FOR NEW LIGHTING CIRCUITS AND 1 TO 6 FOR RECEPTACLE OUTLET CIRCUITS.
-  UNIT DUCT, 600V, 4-1/C NO 8, 3-1/C NO 2 AND 1/C NO 2 GROUND 600V (XLP-TYPE-USE) 1.5" DIAMETER POLYTHYLENE (X8163577).
-  GROUND ROD 5/8" X 10'.
-  PROPOSED HANDHOLE.
-  PUSHED GALVANIZED RIGID STEEL CONDUIT 4" DIA IN UNIT DUCT, 600V, 4-1/C NO 8, 3-1/C NO 2 AND 1/C NO 2 GROUND 600V (XLP-TYPE-USE) IN 1.5" DIA POLYETHYLENE (X81635774).
-  LIGHT POLE "CONTROLLER, CIRCUIT/STA/OFFSET FROM CENTERLINE OF CONSTRUCTION".

GENERAL NOTE:

- THE CONTRACTOR SHALL MAKE SPECIAL NOTE OF THE SPECIFIED REQUIREMENTS FOR BURIED WARNING TAPE, SPECIFIED AS PART OF "TRENCH AND BACKFILL FOR ELECTRICAL WORK". THE INSTALLATION OF THE TAPE SHALL BE INSPECTED BY ENGINEER PRIOR TO BACKFILL.
- ALL CABLES SHALL BE CONTINUOUS BETWEEN ABOVE GROUND SPLICE CONNECTIONS. NO UNDERGROUND SPLICES SHALL BE ALLOWED
- ALL RIGID STEEL CONDUITS SHALL BE CONTINUOUS. NO CONDUIT SPLICING SHALL BE ALLOWED.
- ALL STREET LIGHTING CONDUITS SHALL BE MINIMUM OF 30-INCHES DEEP.
- ALL DISTURBED AREAS SHALL BE BACKFILLED AND RESTORED WITH APPROPRIATE MATERIALS FOR PAVED OR UNPAVED AREAS.
- USE LUMINAIRE [TR20-009]-135W80LED4K-G3-LE2S-VOLT-DMG-BE6TX ---- MAKE LUMEC. INSTALLATION SHALL BE PER MANUFACTURERS RECOMMENDATION.
- INSTALL PROPOSED LIGHT POLE CATALOG NUMBER ATR106V-38-BABS30.5(2)-CAP3-GFII-VD-BE6TX MAKE LUMEC. INSTALLATION SHALL BE PER MANUFACTURERS RECOMMENDATION. COORDINATE POLE ANCHOR PLATE DIMENSIONS WITH HELIX DIMENSIONS PROVIDED.
- FOR LIGHTING GENERAL NOTES SEE SHEET NO. 113

LOAD TABLE:

PROPOSED LIGHTING LOAD TABLE (240V)					
CIRCUIT	RED PHASE		CIRCUIT	RED PHASE	
	AMPS	WATTS		AMPS	WATTS
A	3.94	945	B	3.94	945
C	3.94	945	D	3.94	945
E	3.94	945	F	3.94	945
TOTAL LOAD FOR NEW LIGHTING = 23.6 AMPS					

MODEL Default
FILE Name: Projects\19014\001\1\CA0DDCAD_Sheets\19014-shr-PR-114-01.dgn




USER NAME = mohammed.ait	DESIGNED - RH	REVISED -
	DRAWN - CW	REVISED -
PLOT SCALE = 100.0000 ' / In.	CHECKED - TDM	REVISED -
PLOT DATE = 9/4/2025	DATE - 01/11/2025	REVISED -

STATE OF ILLINOIS
DEPARTMENT OF TRANSPORTATION

WOODFIELD ROAD
PROPOSED LIGHTING DETAILS

SCALE: 1" = 50' SHEET 1 OF 3 SHEETS STA. 100+00 TO STA. 114+00

F.A.U RTE.	SECTION	COUNTY	TOTAL SHEETS	SHEET NO.
3073	20-00134-00-R5	COOK	166	121
CONTRACT NO. 61143				
ILLINOIS FED. AID PROJECT				

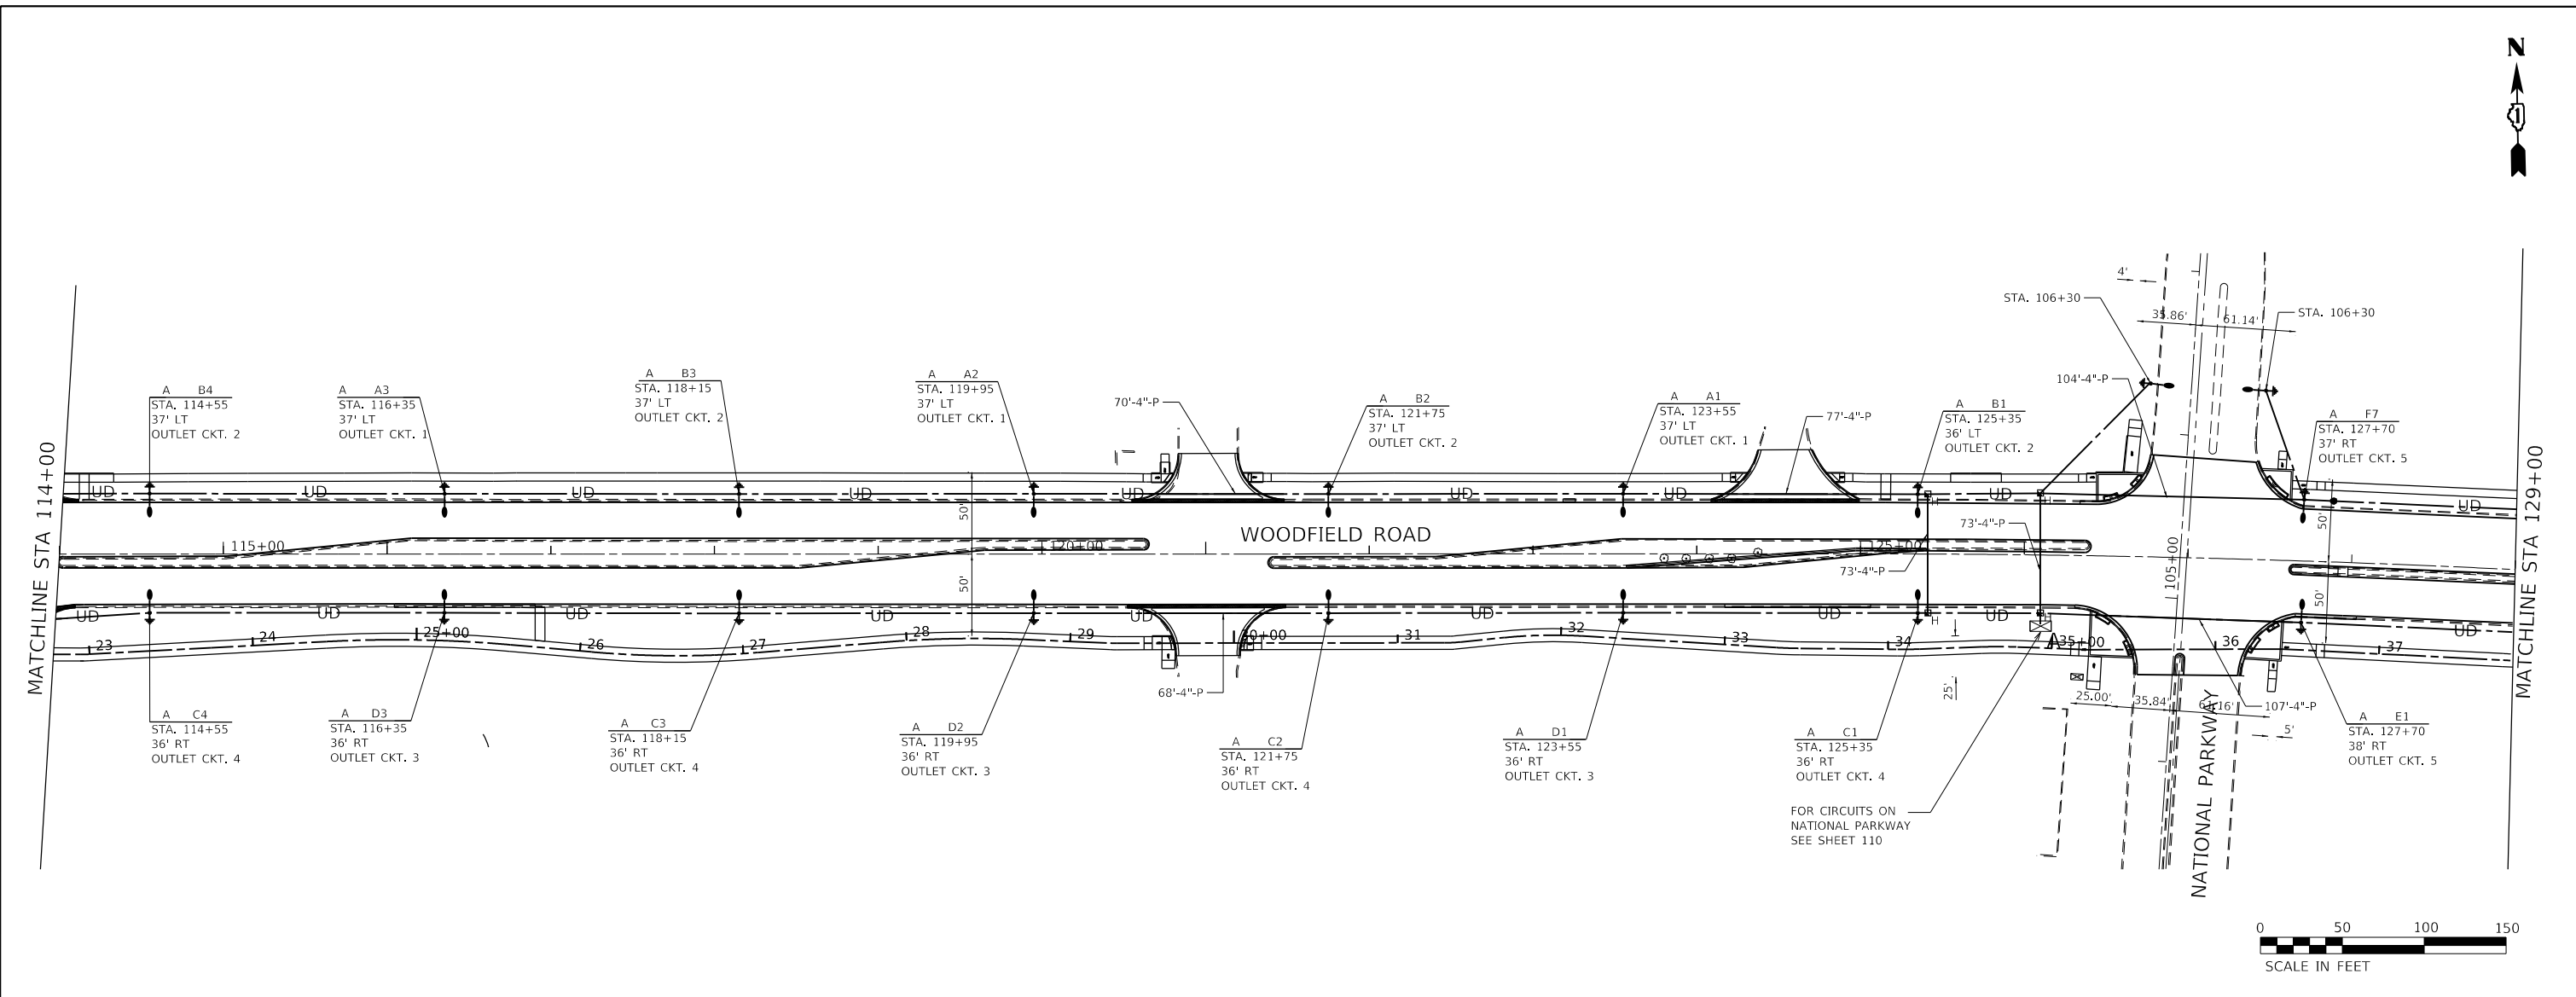

LIGHTING LEGEND:

- PROPOSED LIGHTING UNIT WITH POLE BASE LOCATED 5-FT BEHIND PROPOSED EDGE OF PAVEMENT. 35-FT MOUNTING HEIGHT, MAST ARM LENGTH 3.5', 135W LED LUMINAIRE PHILIPS [TR20-009]-135W80LED4K-G3-LE2S-VOLT-DMG-BE6TX FESTOON OUTLET - 20AMP GF/WEATHER PROOF COVER SEE DETAILS SHEET.
- EXISTING LIGHTING CONTROLLER CABINET 120/240V SINGLE PHASE 3W 225AMP TO BE USED FOR PROPOSED LIGHTING FOR CIRCUITS A, B, C, D, E, AND F. USE EXISTING 2P BREAKERS FOR NEW LIGHTING CIRCUITS AND 1 TO 6 FOR RECEPTACLE OUTLET CIRCUITS.
- UNIT DUCT, 600V, 4-1/C NO 8, 3-1/C NO 2 AND 1/C NO 2 GROUND (XLP-TYPE-USE) 1.5" DIAMETER POLYTHYLENE (X8163577).
- GROUND ROD 5/8" X 10'.
- PROPOSED HANDHOLE.
- "P" PUSHED GALVANIZED RIGID STEEL CONDUIT 4" DIA IN UNIT DUCT, 600V, 4-1/C NO 8, 3-1/C NO 2 AND 1/C NO 2 GROUND 600V (XLP-TYPE-USE) IN 1.5" DIA POLYETHYLENE (X8163577).
- "CONTROLLER" CKT STA. XXX+XX OFF, LT/RT LIGHT POLE "CONTROLLER, CIRCUIT/STA/OFFSET FROM CENTERLINE OF CONSTRUCTION".

CONSTRUCTION KEYNOTES

- EXISTING LIGHTING CONTROLLER (A) TO BE USED FOR ALL NEW LIGHTING BETWEEN MEACHAM AND PLUM GROVE

GENERAL NOTE:

- THE CONTRACTOR SHALL MAKE SPECIAL NOTE OF THE SPECIFIED REQUIREMENTS FOR BURIED WARNING TAPE, SPECIFIED AS PART OF "TRENCH AND BACKFILL FOR ELECTRICAL WORK". THE INSTALLATION OF THE TAPE SHALL BE INSPECTED BY ENGINEER PRIOR TO BACKFILL.
- ALL CABLES SHALL BE CONTINUOUS BETWEEN ABOVE GROUND SPLICE CONNECTIONS. NO UNDERGROUND SPLICES SHALL BE ALLOWED
- ALL RIGID STEEL CONDUITS SHALL BE CONTINUOUS. NO CONDUIT SPLICING SHALL BE ALLOWED.
- ALL STREET LIGHTING CONDUITS SHALL BE MINIMUM OF 30-INCHES DEEP.
- ALL DISTURBED AREAS SHALL BE BACKFILLED AND RESTORED WITH APPROPRIATE MATERIALS FOR PAVED OR UNPAVED AREAS.
- USE LUMINAIRE [TR20-009]-135W80LED4K-G3-LE2S-VOLT-DMG-BE6TX ---- MAKE LUMEC. INSTALLATION SHALL BE PER MANUFACTURERS RECOMMENDATION.
- INSTALL PROPOSED LIGHT POLE CATALOG NUMBER ATR106V-38-BABS30.5(2)-CAP3-GFII-VD-BE6TX MAKE LUMEC. INSTALLATION SHALL BE PER MANUFACTURERS RECOMMENDATION. COORDINATE POLE ANCHOR PLATE DIMENSIONS WITH HELIX DIMENSIONS PROVIDED.
- FOR LIGHTING GENERAL NOTES SEE SHEET NO. 113

LOAD TABLE:

PROPOSED LIGHTING LOAD TABLE (240V)					
CIRCUIT	RED PHASE		CIRCUIT	RED PHASE	
	AMPS	WATTS		AMPS	WATTS
A	3.94	945	B	3.94	945
C	3.94	945	D	3.94	945
E	3.94	945	F	3.94	945
TOTAL LOAD FOR NEW LIGHTING = 23.6 AMPS					

MODEL: Default
FILE NAME: Projects\190114\01\CAD\CAD Sheets\190114-stp-pr-light-02.dgn




USER NAME	= mohammed.all	DESIGNED	- RH	REVISED	-
		DRAWN	- CW	REVISED	-
PLOT SCALE	= 100,0000 ' / in.	CHECKED	- TDM	REVISED	-
PLOT DATE	= 9/2/2025	DATE	- 01/11/2025	REVISED	-

STATE OF ILLINOIS
DEPARTMENT OF TRANSPORTATION



WOODFIELD ROAD
PROPOSED LIGHTING DETAILS

SCALE: 1" = 50' SHEET 2 OF 3 SHEETS STA. 114+00 TO STA. 129+00

F.A.U RTE.	SECTION	COUNTY	TOTAL SHEETS	SHEET NO.
3073	20-00134-00-R5	COOK	166	122
CONTRACT NO. 61L43				
ILLINOIS FED. AID PROJECT				

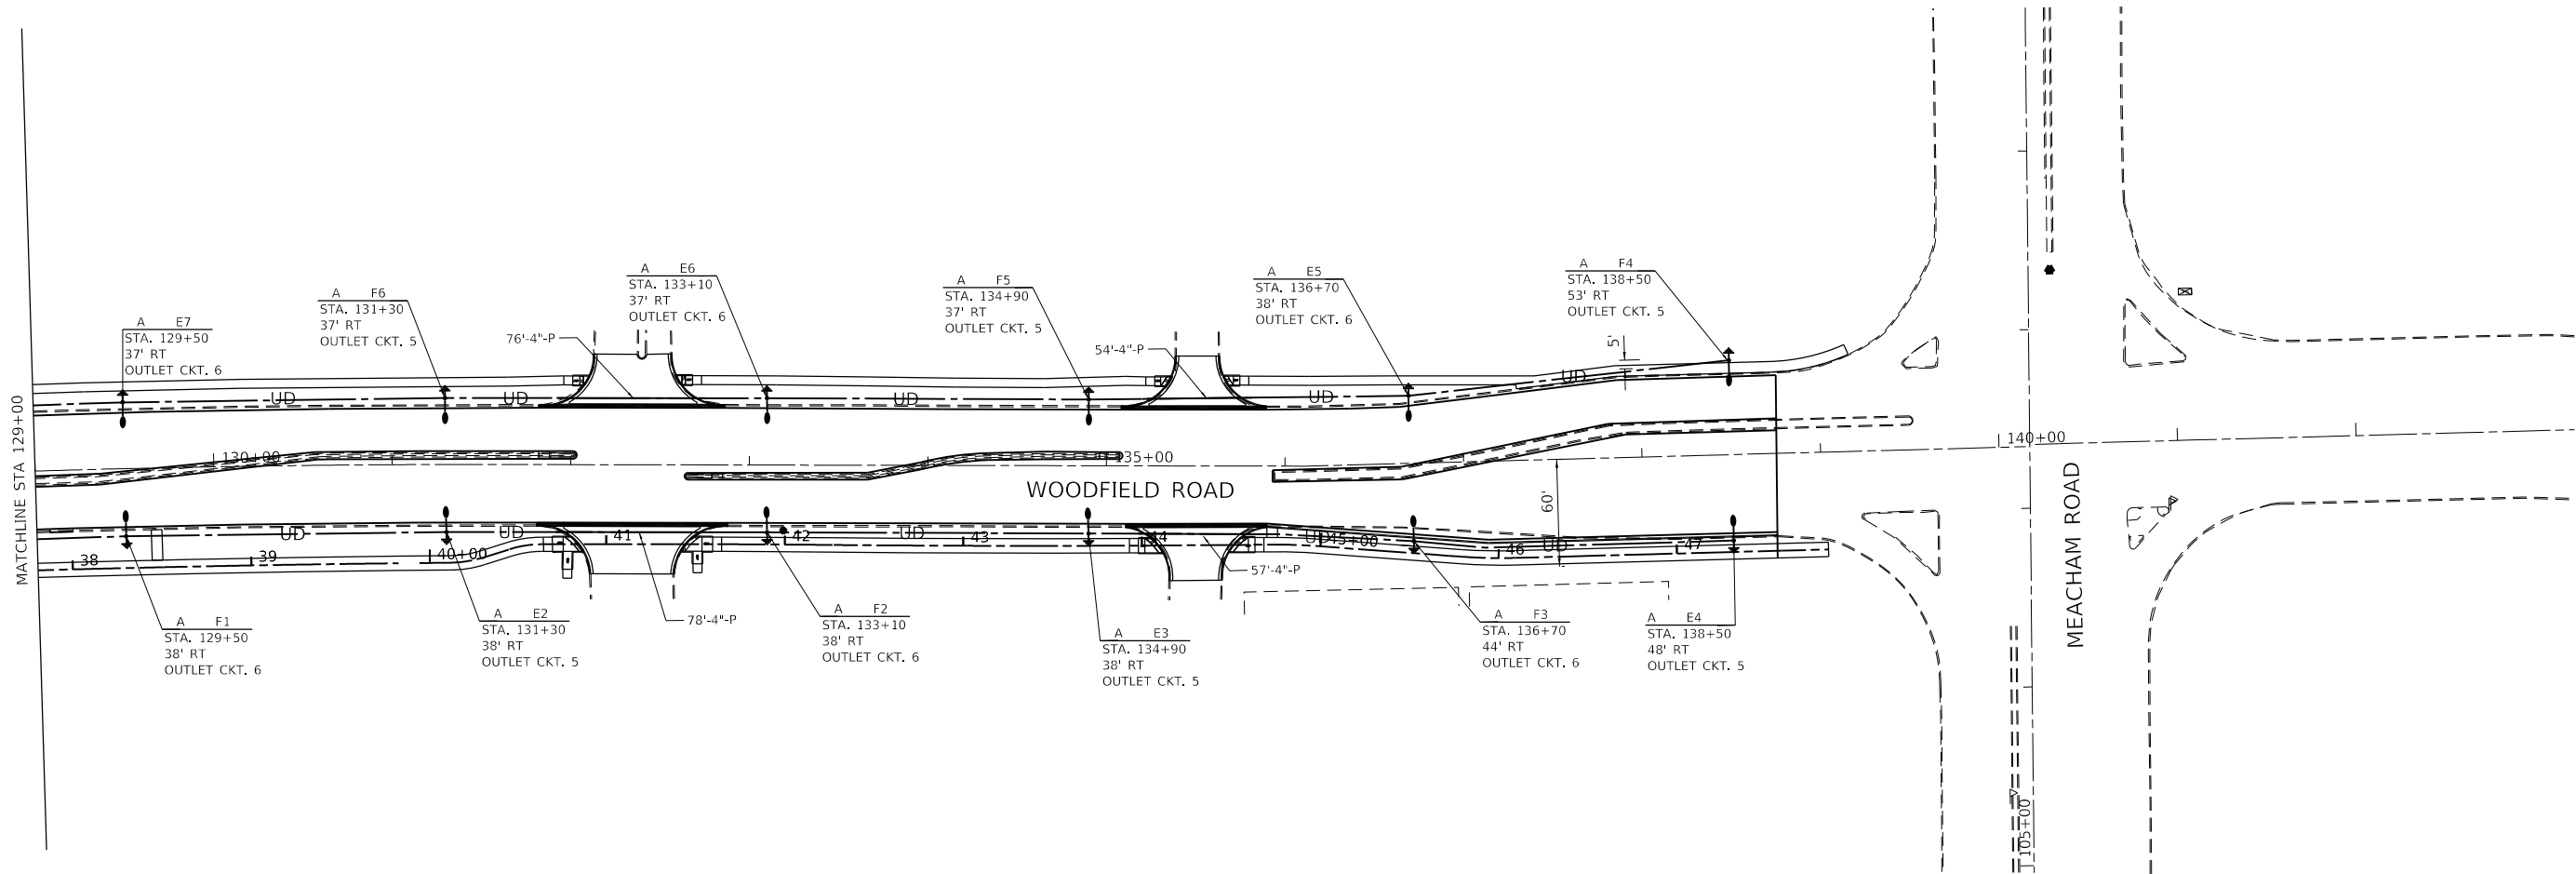

LIGHTING LEGEND:

  -  PROPOSED LIGHTING UNIT WITH POLE BASE LOCATED 5-FT BEHIND PROPOSED EDGE OF PAVEMENT. 35-FT MOUNTING HEIGHT, MAST ARM LENGTH 3.5', 135W LED LUMINAIRE PHILIPS [TR20-009]-135W80LED4K-G3-LE2S-VOLT-DMG-BE6TX FESTOON OUTLET - 20AMP GFI/WEATHER PROOF COVER SEE DETAILS SHEET.
-  EXISTING LIGHTING CONTROLLER CABINET 120/240V SINGLE PHASE 3W 225AMP TO BE USED FOR PROPOSED LIGHTING FOR CIRCUITS A, B, C, D, E, AND F. USE EXISTING 2P BREAKERS FOR NEW LIGHTING CIRCUITS AND 1 TO 6 FOR RECEPTACLE OUTLET CIRCUITS.
-  UNIT DUCT, 600V, 4-1/C NO 8, 3-1/C NO 2 AND 1/C NO 2 GROUND, (XLP-TYPE-USE) 1.5" DIAMETER POLYTHYLENE (X8163577).
-  GROUND ROD 5/8" X 10'.
-  PROPOSED HANDHOLE.
-  PUSHED GALVANIZED RIGID STEEL CONDUIT 4" DIA IN UNIT DUCT, 600V, 4-1/C NO 8, 3-1/C NO 2 AND 1/C NO 2 GROUND (XLP-TYPE-USE) IN 1.5" DIA POLYETHYLENE (X8163577).
-  LIGHT POLE "CONTROLLER, CIRCUIT/STA/OFFSET FROM CENTERLINE OF CONSTRUCTION".

GENERAL NOTE:

- 1- THE CONTRACTOR SHALL MAKE SPECIAL NOTE OF THE SPECIFIED REQUIREMENTS FOR BURIED WARNING TAPE, SPECIFIED AS PART OF "TRENCH AND BACKFILL FOR ELECTRICAL WORK". THE INSTALLATION OF THE TAPE SHALL BE INSPECTED BY ENGINEER PRIOR TO BACKFILL.
2. ALL CABLES SHALL BE CONTINUOUS BETWEEN ABOVE GROUND SPLICE CONNECTIONS. NO UNDERGROUND SPLICES SHALL BE ALLOWED
3. ALL RIGID STEEL CONDUITS SHALL BE CONTINUOUS. NO CONDUIT SPLICING SHALL BE ALLOWED.
4. ALL STREET LIGHTING CONDUITS SHALL BE MINIMUM OF 30-INCHES DEEP.
5. ALL DISTURBED AREAS SHALL BE BACKFILLED AND RESTORED WITH APPROPRIATE MATERIALS FOR PAVED OR UNPAVED AREAS.
6. USE LUMINAIRE [TR20-009]-135W80LED4K-G3-LE2S-VOLT-DMG-BE6TX ---- MAKE LUMEC. INSTALLATION SHALL BE PER MANUFACTURERS RECOMMENDATION.
7. INSTALL PROPOSED LIGHT POLE CATALOG NUMBER ATR106V-38-BABS30.5(2)-CAP3-GFII-VD-BE6TX MAKE LUMEC. INSTALLATION SHALL BE PER MANUFACTURERS RECOMMENDATION. COORDINATE POLE ANCHOR PLATE DIMENSIONS WITH HELIX DIMENSIONS PROVIDED.
8. FOR LIGHTING GENERAL NOTES SEE SHEET NO. 113

LOAD TABLE:

PROPOSED LIGHTING LOAD TABLE (240V)					
CIRCUIT	RED PHASE		CIRCUIT	RED PHASE	
	AMPS	WATTS		AMPS	WATTS
A	3.94	945	B	3.94	945
C	3.94	945	D	3.94	945
E	3.94	945	F	3.94	945
TOTAL LOAD FOR NEW LIGHTING = 23.6 AMPS					

MODEL: Default
FILE: 20-00134-00-RS-03.dgn
PROJECT: 20-00134-00-RS-03.dgn
SHEET: 123
DATE: 9/2/2025



USER NAME = mohammed.ah	DESIGNED - RH	REVISED -
	DRAWN - CW	REVISED -
PLOT SCALE = 100.0000 ' / in.	CHECKED - TDM	REVISED -
PLOT DATE = 9/2/2025	DATE - 01/11/2025	REVISED -

**STATE OF ILLINOIS
DEPARTMENT OF TRANSPORTATION**

**WOODFIELD ROAD
PROPOSED LIGHTING DETAILS**

SCALE: 1" = 50' SHEET 3 OF 3 SHEETS STA. 129+00 TO STA. 143+00


F.A.U RTE.	SECTION	COUNTY	TOTAL SHEETS	SHEET NO.
3073	20-00134-00-RS	COOK	166	123
CONTRACT NO. 61L43				
ILLINOIS FED. AID PROJECT				




1. THE COLOR FINISH OF POLE, LUMINAIRE, AND MAST ARM SHALL BE AS APPROVED BY CITY OF SCHAUMBURG.



(NOT TO SCALE)

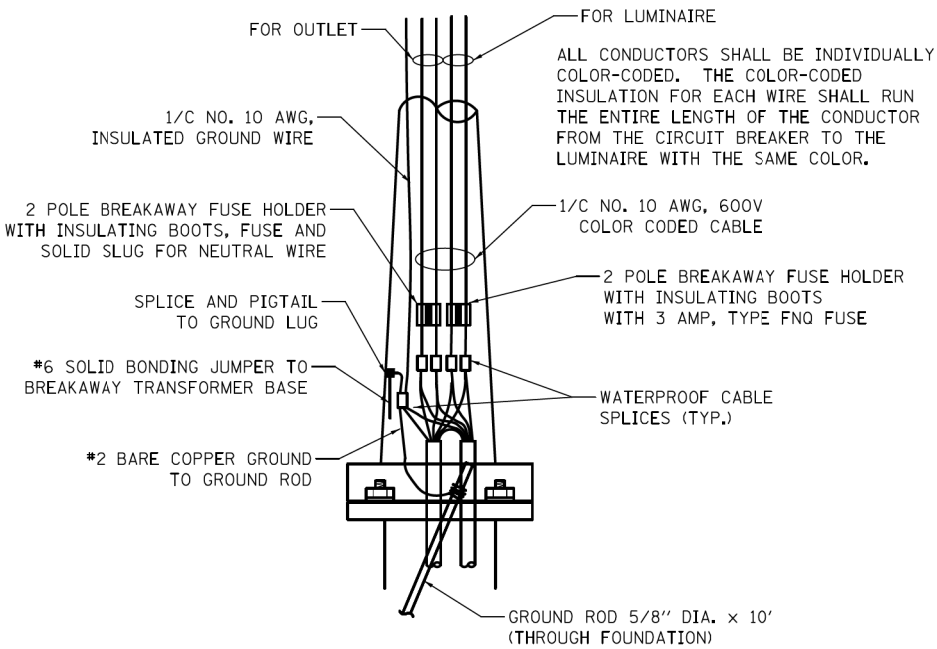


ROADWAY POLE HANDHOLE WIRING DIAGRAM

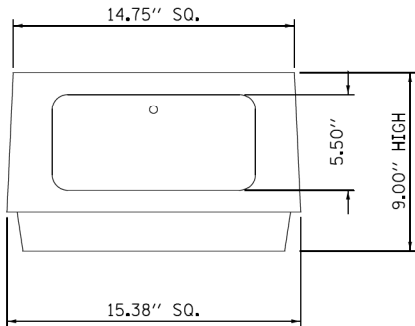


NOTES:

- HARDWARE: CARRIAGE BOLTS SHALL BE USED WITH FLAT WASHER, LOCK WASHER, AND NUTS. NO THREADED ROD ALLOWED.
- GROUNDING: AREA WHERE THE GROUND WIRE ATTACHES TO TRANSFORMER BASE MUST BE SCRATCHED TO ENSURE EFFECTIVE BONDING.
- TRANSFORMER BASE SHALL BE POWDER COATED TO MATCH POLE COLOR.
- DIMENSIONS ARE NOMINAL AND MAY BE ADJUSTED TO MATCH MANUFACTURER'S SPECIFICATIONS.

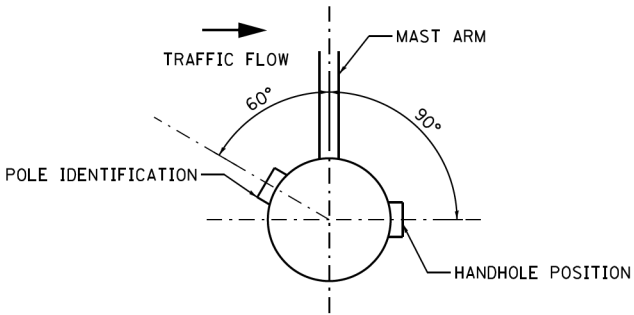

POSITION OF HANDHOLE AND POLE IDENTIFICATION

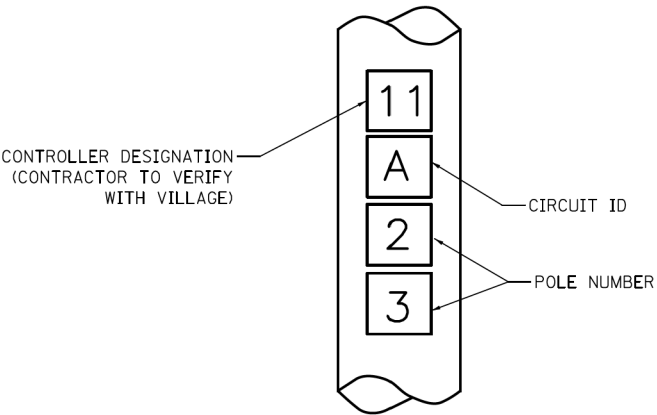

NOTES:

- 4" HIGH WHITE LETTERS SCREENED ON A 4-1/2" X 4" RED, PRESSURE SENSITIVE AND REFLECTIVE BACKGROUND.
- THE CONTRACTOR SHALL COORDINATE LIGHT POLE AND CONTROLLER IDENTIFICATION NUMBERS WITH THE VILLAGE PRIOR TO CONSTRUCTION.

POLE IDENTIFICATION

MODEL: Default
FILE: 20-00134-00-RS.dgn
PROJECT: 20-00134-00-RS
SHEET: 166 OF 125



USER NAME	= mohammed.ait	DESIGNED -	RH	REVISED -	
		DRAWN -	CW	REVISED -	
PLOT SCALE	= 100.0000 ' / in.	CHECKED -	TDM	REVISED -	
PLOT DATE	= 9/2/2025	DATE	= 01/11/2025	REVISED -	

STATE OF ILLINOIS
DEPARTMENT OF TRANSPORTATION

WOODFIELD ROAD
LIGHTING DETAILS

SCALE: N/A SHEET 2 OF 3 SHEETS STA. N/A TO STA. N/A

F.A.U. RTE.	SECTION	COUNTY	TOTAL SHEETS	SHEET NO.
3073	20-00134-00-RS	COOK	166	125
CONTRACT NO. 61L43				
ILLINOIS FED. AID PROJECT				

NOTES:


1.

IN GRASS COVERED AREAS, THE BACKFILL MAY BE COMPACTED EARTH.
2.


TRENCHES WITHIN 2' OF PROPOSED OR EXISTING STREETS, DRIVEWAYS, OR SIDEWALKS WILL BE BACKFILLED WITH COMPACTED FA-6 SAND OR LIMESTONE SCREENINGS.
3.

WARNING TAPE WILL BE RED WITH BLACK LETTERING TO READ "CAUTION - ELECTRIC LINE BURIED BELOW".
4.

ALL GRASS COVERED AREAS DISTURBED DURING CONSTRUCTION WILL BE RESTORED WITH 4" OF TOPSOIL AND SOD.

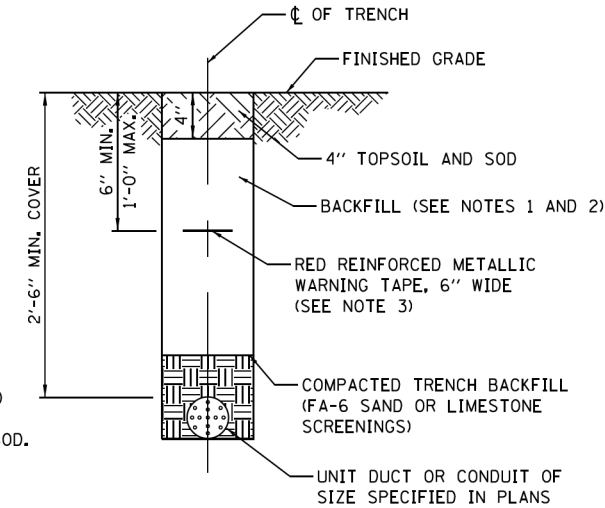

TYPICAL TRENCH CROSS SECTION

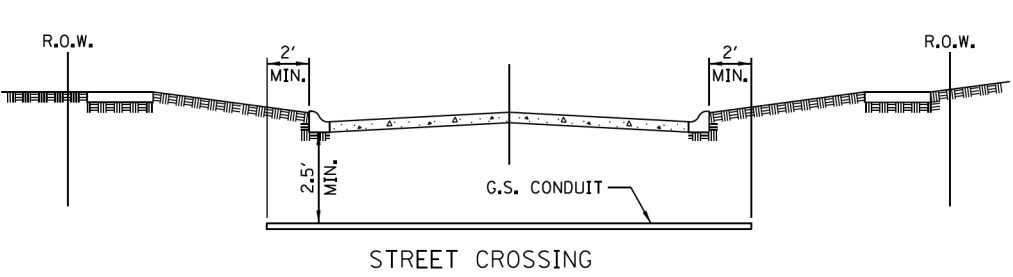

NOTES

1.


PAVEMENT INCLUDES ROADS, DRIVEWAYS, SIDEWALKS, AND BIKE PATHS.
2.

CONDUIT SHALL BE HEAVY WALL RIGID GALVANIZED STEEL CONDUIT, MINIMUM 2" DIAMETER.
3.

CONDUIT SHALL EXTEND A MINIMUM OF 2 FT. BEYOND BACK OF CURB OR EDGE OF PAVEMENT.
4.


CONDUIT SHALL BE A MINIMUM OF 2.5 FT. BELOW BOTTOM OF PAVEMENT.

ELECTRICAL CONDUIT UNDER PAVEMENT

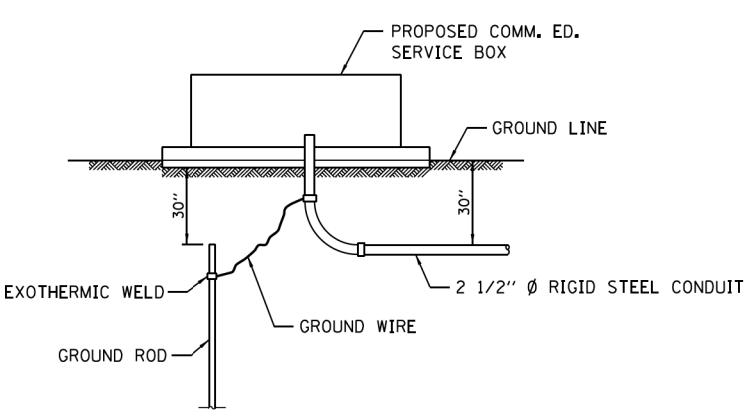

PROPOSED SERVICE INSTALLATION

NOTE: GROUND ROD, GROUND CLAMPS & GROUND WIRE TO BE IN ACCORDANCE WITH COMM. ED. REQUIREMENTS.

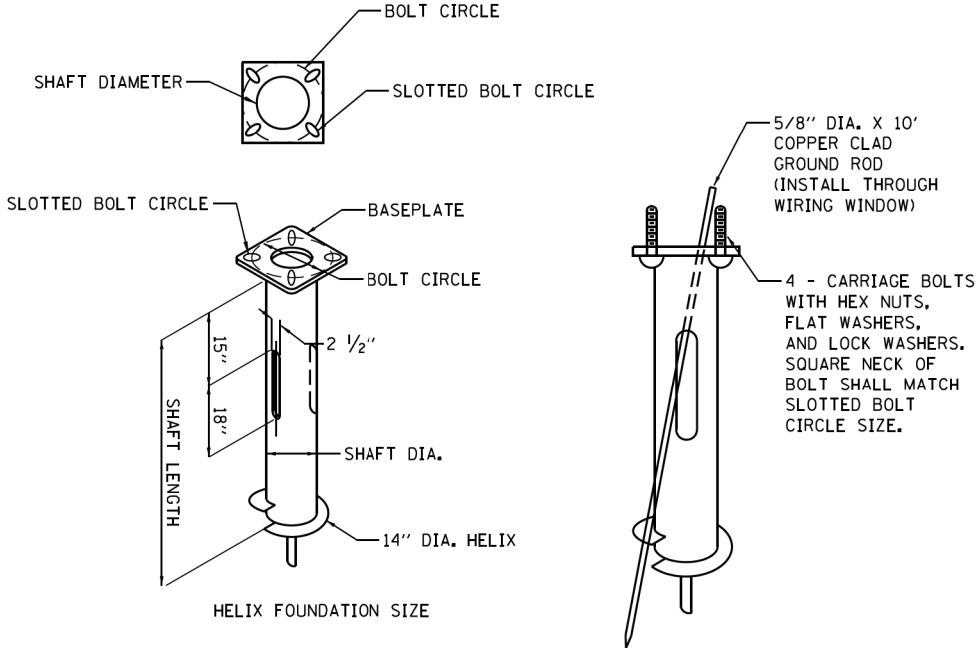

POLE MOUNTING HEIGHT	BOLT CIRCLE	SHAFT DIAMETER	SHAFT LENGTH	BASEPLATE
30 FT.	11 1/2"	8 5/8"	6 FT.	12" X 12" X 1"
31 FT. - 35 FT.	11 1/2"	8 5/8"	6 FT.	12" X 12" X 1"
36 FT. - 40 FT.	15"	8 5/8"	6 FT.	15" X 15" X 1 1/4"
41 FT. - 45 FT.	15"	8 5/8"	6 FT.	15" X 15" X 1 1/4"
46 FT. - 50 FT.	15"	10"	8 FT.	15" X 15" X 1 1/4"

NOTES FOR METAL FOUNDATION

1.

METAL FOUNDATION SHALL BE THE FOUNDATION USED FOR ALL LIGHTING AND DECORATIVE LIGHTING UNITS UNLESS CONDITIONS IN THE FIELD MAKES IT IMPOSSIBLE TO USE METAL FOUNDATIONS, THEN AN OFFSET FOUNDATION SHALL BE USED WITH ENGINEER APPROVAL.
2.

ALL MATERIAL SHALL BE GALVANIZED ACCORDING TO AASHTO M111, UNLESS OTHERWISE SPECIFIED.
3.

ALL WELDS SHALL BE CONTINUOUS AND NOT LESS THAN 1/4" FILLET WELDS. THE WELDED FOUNDATION SHALL BE CAPABLE OF WITHSTANDING 10,000 FT/LBS OF INSTALLATION TORQUE APPLIED ABOUT THE AXIS OF THE FOUNDATION.
4.

FABRICATE TWO SLOTS IN THE SHAFT AT 180 DEGREES FOR UNIT DUCTS AND CABLES ENTERING AND LEAVING THE POLE FOUNDATION.
5.

TOP PLATE SHALL BE PERMANENTLY MARKED WITH THE CABLING SLOT LOCATIONS.
6.

HELIX FOUNDATION SHALL BE INSTALLED VERTICAL AND THE BASEPLATE SHALL BE IN LEVEL. THE BREAKAWAY COUPLINGS AND HARDWARE SHALL NOT BE USED TO ALIGN THE POLE INSTALLATION.
7.

THE CABLE TRENCH SHALL BE BACKFILLED AND FIRMLY COMPACTED BEFORE THE INSTALLATION OF THE LIGHT POLE.
8.

THE CONTRACTOR SHALL COORDINATE EXTENSION OF ANCHOR BOLTS ABOVE TOP OF THE BASEPLATE WITH THE BREAKAWAY DEVICE MANUFACTURER'S REQUIREMENTS.
9.

ANY VOIDS WITHIN THE METAL FOUNDATION SHALL BE FILLED WITH SAND.
10.

METAL FOUNDATIONS SHALL BE INSTALLED IN UNDISTURBED SOIL. PREDRILLING A PILOT HOLE AND/OR BACKFILLING AROUND THE FOUNDATION IS NOT ALLOWED.
11.

GROUND ROD, 5/8" DIA. x 10', THROUGH FOUNDATION WILL BE REQUIRED AND INCLUDED ON ALL LIGHT POLE FOUNDATIONS INCLUDING METAL FOUNDATIONS.
12.

THE METAL FOUNDATION SHALL NOT BE INSTALLED TO A TORQUE WHICH EXCEEDS THE MANUFACTURER'S MAXIMUM TORQUE RATING NOR SHALL IT BE INSTALLED TO AN INSTALLATION TORQUE VALUE OF LESS THAN 3,500 FT LB. METAL FOUNDATIONS THAT ARE NOT INSTALLED TO FULL INSTALLATION DEPTH OR DO NOT ACHIEVE THE MINIMUM INSTALLATION TORQUE SHALL BE REMOVED AND REPLACED WITH A CONCRETE FOUNDATION AT NO ADDITIONAL COST.
13.

THE BASEPLATE SHALL BE PERPENDICULAR TO THE SHAFT AXIS (± 1°) AND THE HOLE CENTERLINE SHALL BE CONCENTRIC (± 0.188) TO THE SHAFT AXIS.
14.

THE PILOT POINT AND SHAFT AXIS SHALL BE CONCENTRIC (± 0.125) AND IN LINE (± 2°).
15.

THE BASEPLATE SHALL BE STAMPED WITH THE MANUFACTURERS NAME AND DATE OF MANUFACTURE.
16.

ALL MATERIAL IS TO BE NEW, UNUSED AND MILL TRACEABLE MEETING THE FOLLOWING SPECIFICATIONS:
- BASE PLATE:

AASHTO M 270M, GRADE 36 (M270M, GRADE 250)
- SHAFT:

ASTM A 252 - (LATEST REVISION) GRADE 2, (PHOSPHOROUS 0.04% MAXIMUM, SULFUR 0.05% MAXIMUM)
- HELIX SCREW:

AASHTO M 183 (ASTM A 635) (LATEST REVISION)
- PILOT POINT:

AASHTO M 270 (ASTM A 575) (LATEST REVISION)
- ANCHOR RODS/STUDS:

AASHTO M 314 (ASTM F 1554) (LATEST REVISION)
- HEXAGON NUTS:

AASHTO M 291M (ASTM A 563) GRADE DH, OR AASHTO M 292 (ASTM A 194) GRADE 2H (LATEST REVISION)
- WASHERS:

AASHTO M 293 (ASTM F 436) (LATEST REVISION)

POLE FOUNDATION METAL

HELIX MUST BE FORMED BY MATCHING METAL DIE (SIDE VIEW OF TRUE HELICAL FORM)

STATE OF ILLINOIS
DEPARTMENT OF TRANSPORTATION


WOODFIELD ROAD
LIGHTING DETAILS

SCALE: N/A SHEET 3 OF 3 SHEETS STA. N/A TO STA. N/A


F.A.U RTE.	SECTION	COUNTY	TOTAL SHEETS	SHEET NO.
3073	20-00134-00-RS	COOK	166	126
CONTRACT NO. 61L43				
ILLINOIS FED. AID PROJECT				

USER NAME = mohammed.ah	DESIGNED - RH	REVISED -
	DRAWN - CW	REVISED -
PLOT SCALE = 100.0000 ' / in.	CHECKED - TDM	REVISED -
PLOT DATE = 9/2/2025	DATE - 01/11/2025	REVISED -

FOR INFORMATION ONLY

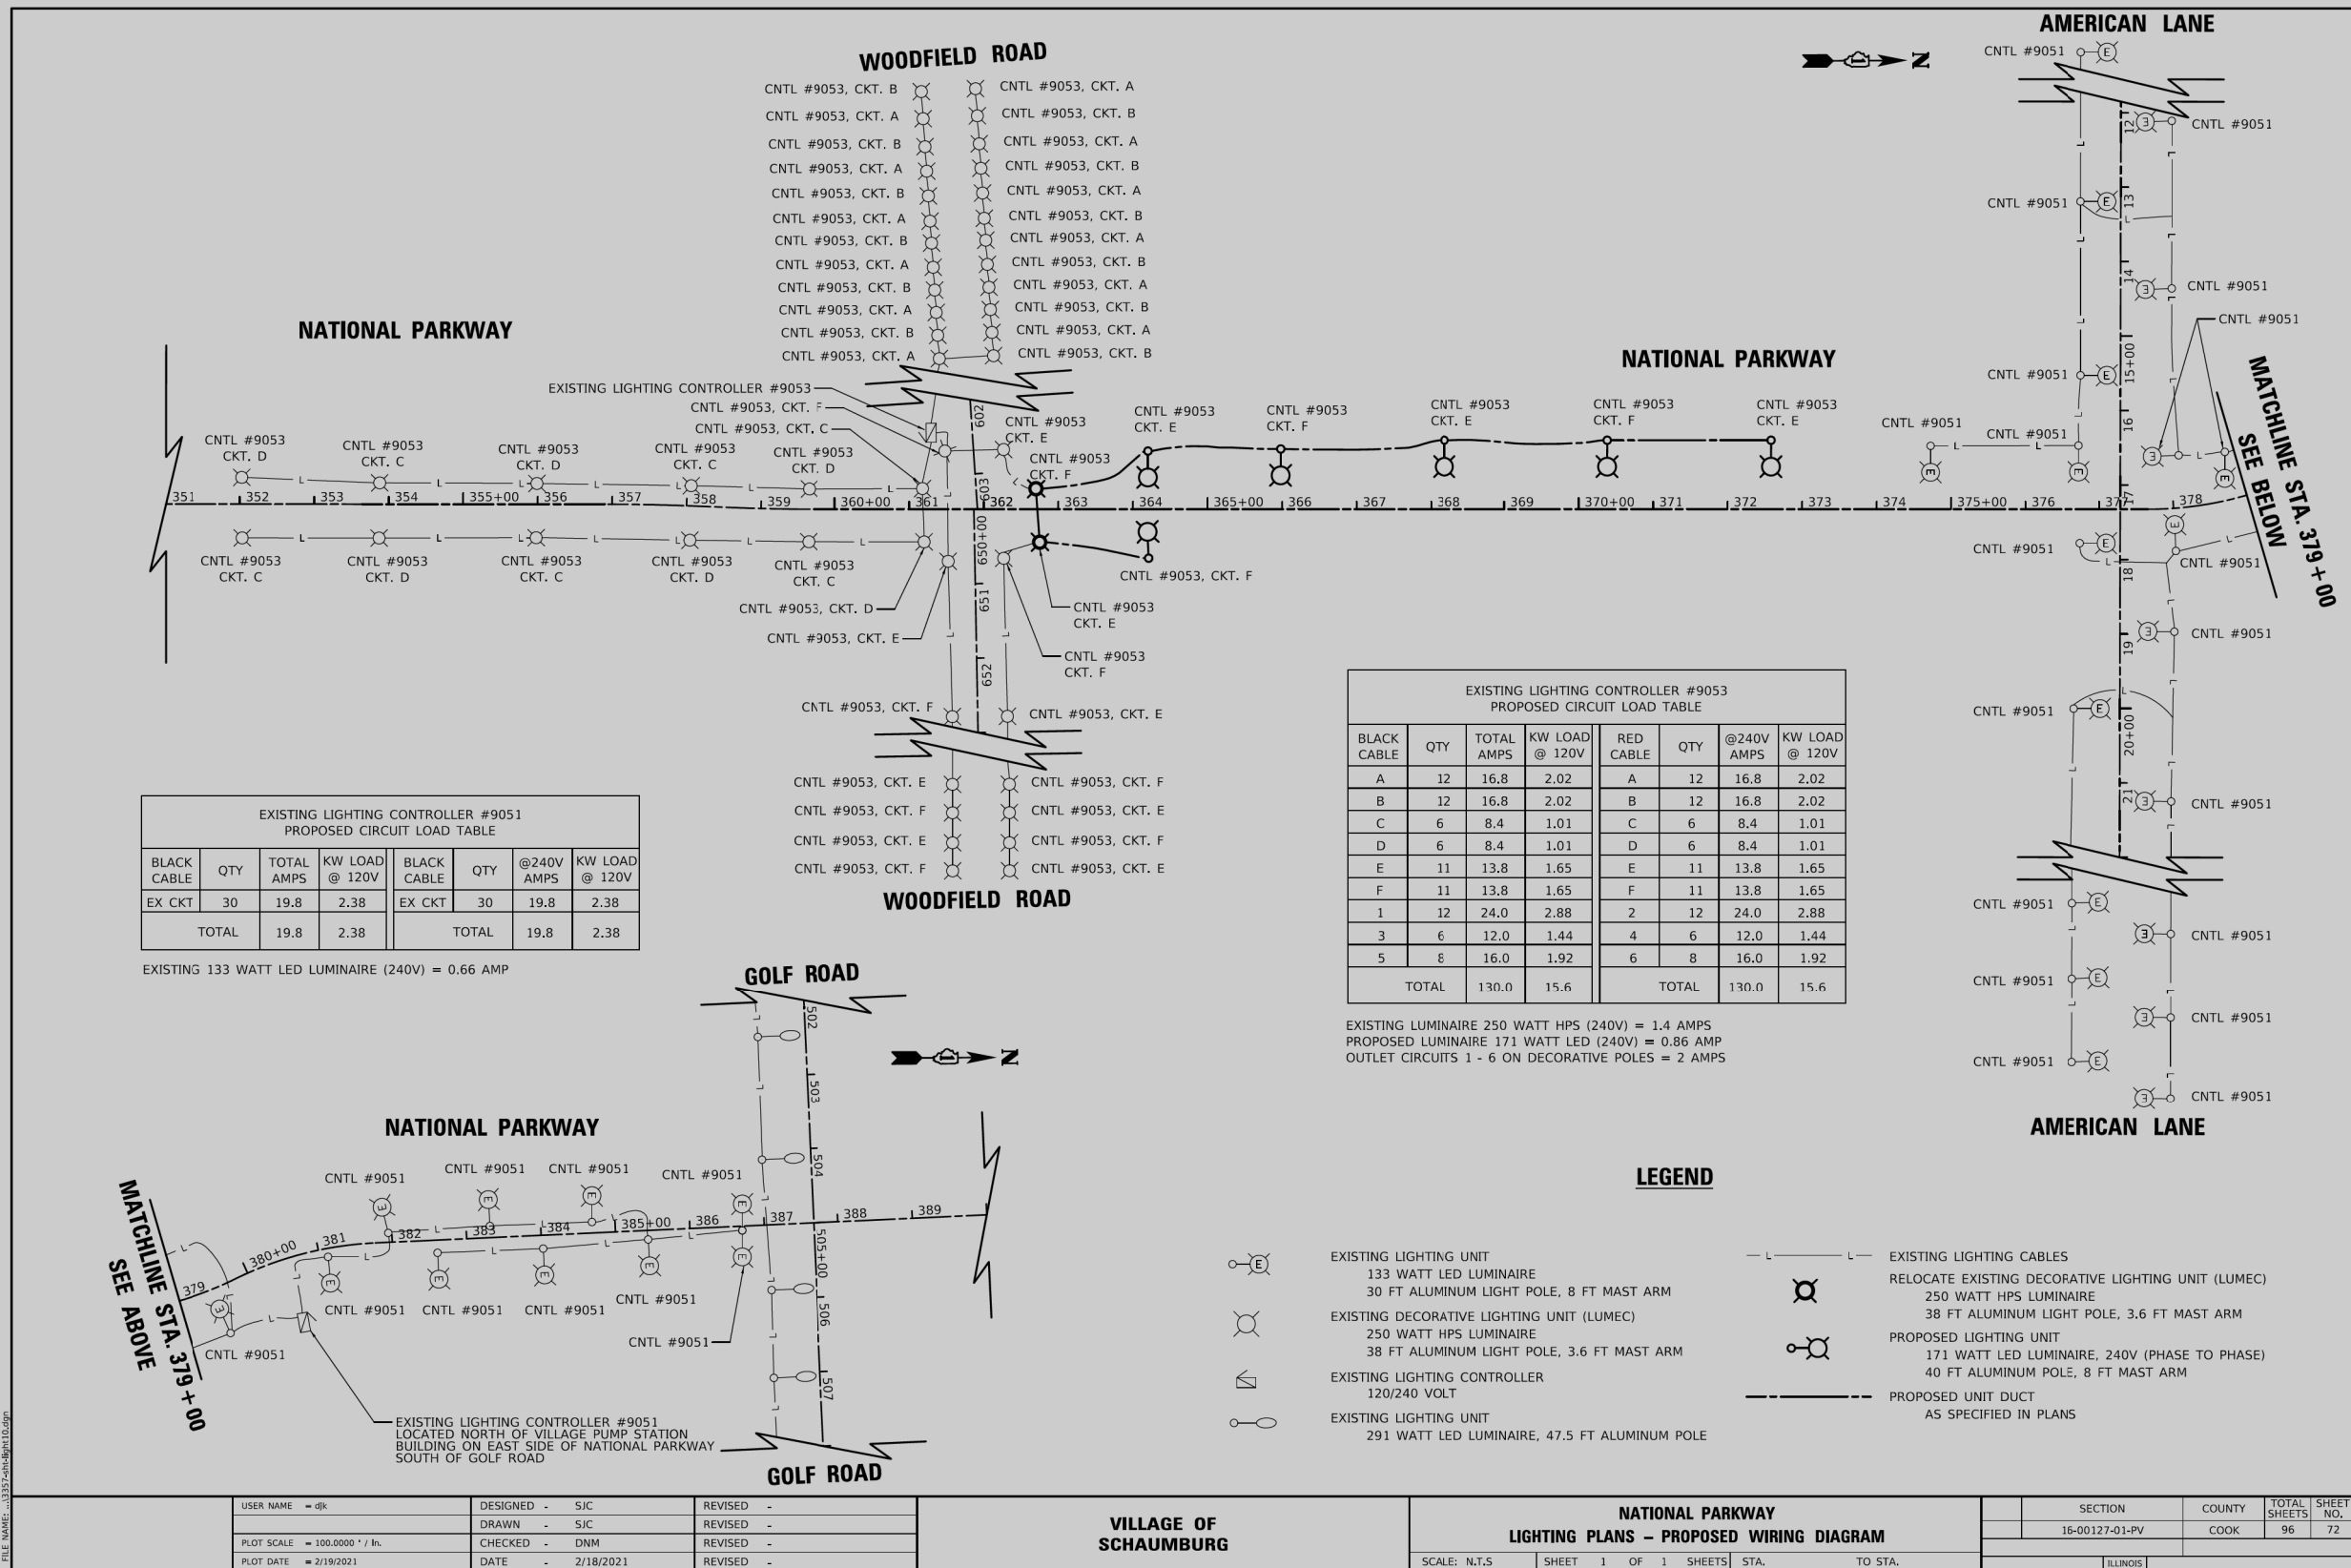


FOR INFORMATION ONLY

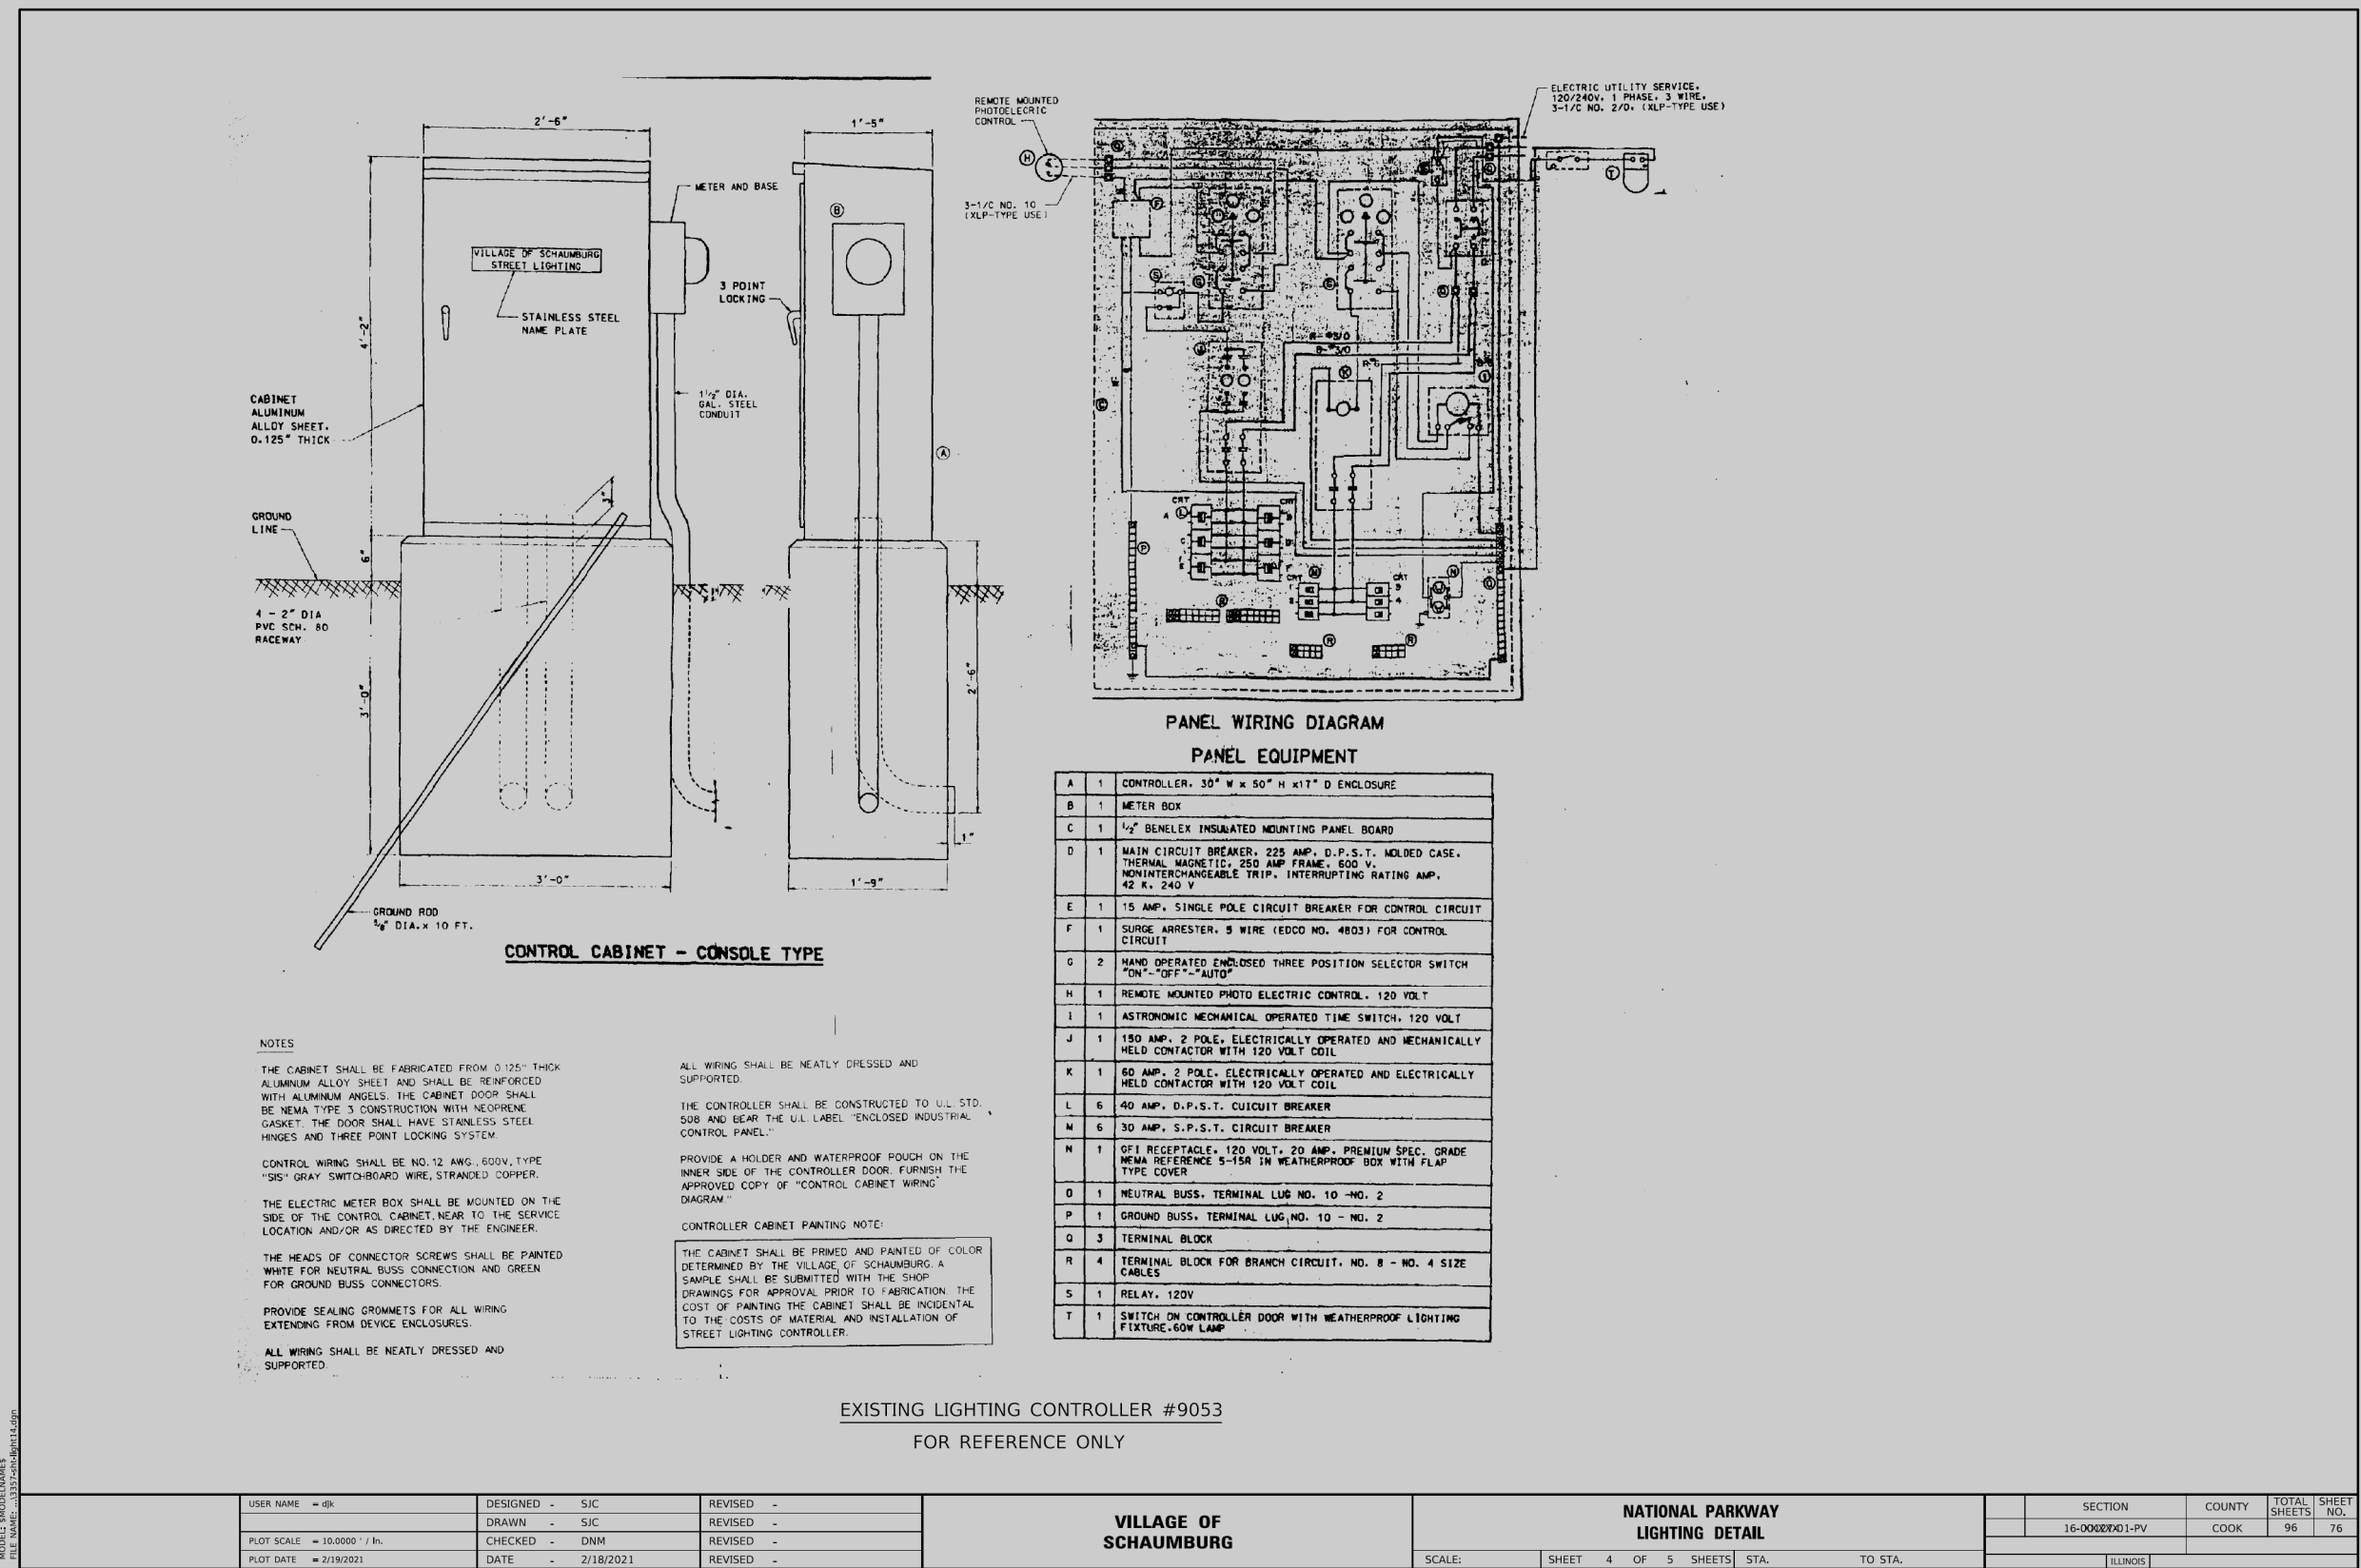

USER NAME = ghk				DESIGNED - SJC				REVISED -				DRAWN - SJC				REVISED -				CHECKED - DNM				REVISED -				PLOT DATE = 2/19/2021				DATE - 2/18/2021				REVISED -			
PLOT SCALE = 10,0000' / in.				PLOT DATE = 2/19/2021				DATE - 2/18/2021				DATE - 2/18/2021				DATE - 2/18/2021				DATE - 2/18/2021				DATE - 2/18/2021				DATE - 2/18/2021				DATE - 2/18/2021				DATE - 2/18/2021			

VILLAGE OF SCHAUMBURG				NATIONAL PARKWAY LIGHTING DETAIL				SECTION 16-0000001-PV				COUNTY COOK				TOTAL SHEETS 96				SHEET NO. 76				SCALE: SHEET 4 OF 5 SHEETS STA. TO STA.				ILLINOIS			
-----------------------	--	--	--	----------------------------------	--	--	--	-----------------------	--	--	--	-------------	--	--	--	-----------------	--	--	--	--------------	--	--	--	---	--	--	--	----------	--	--	--

MODEL: Default
FILE: 16-0000001-PV.dgn
PLOT DATE: 2/19/2021
PLOT SCALE: 10,0000' / in.
PLOT DATE: 2/19/2021

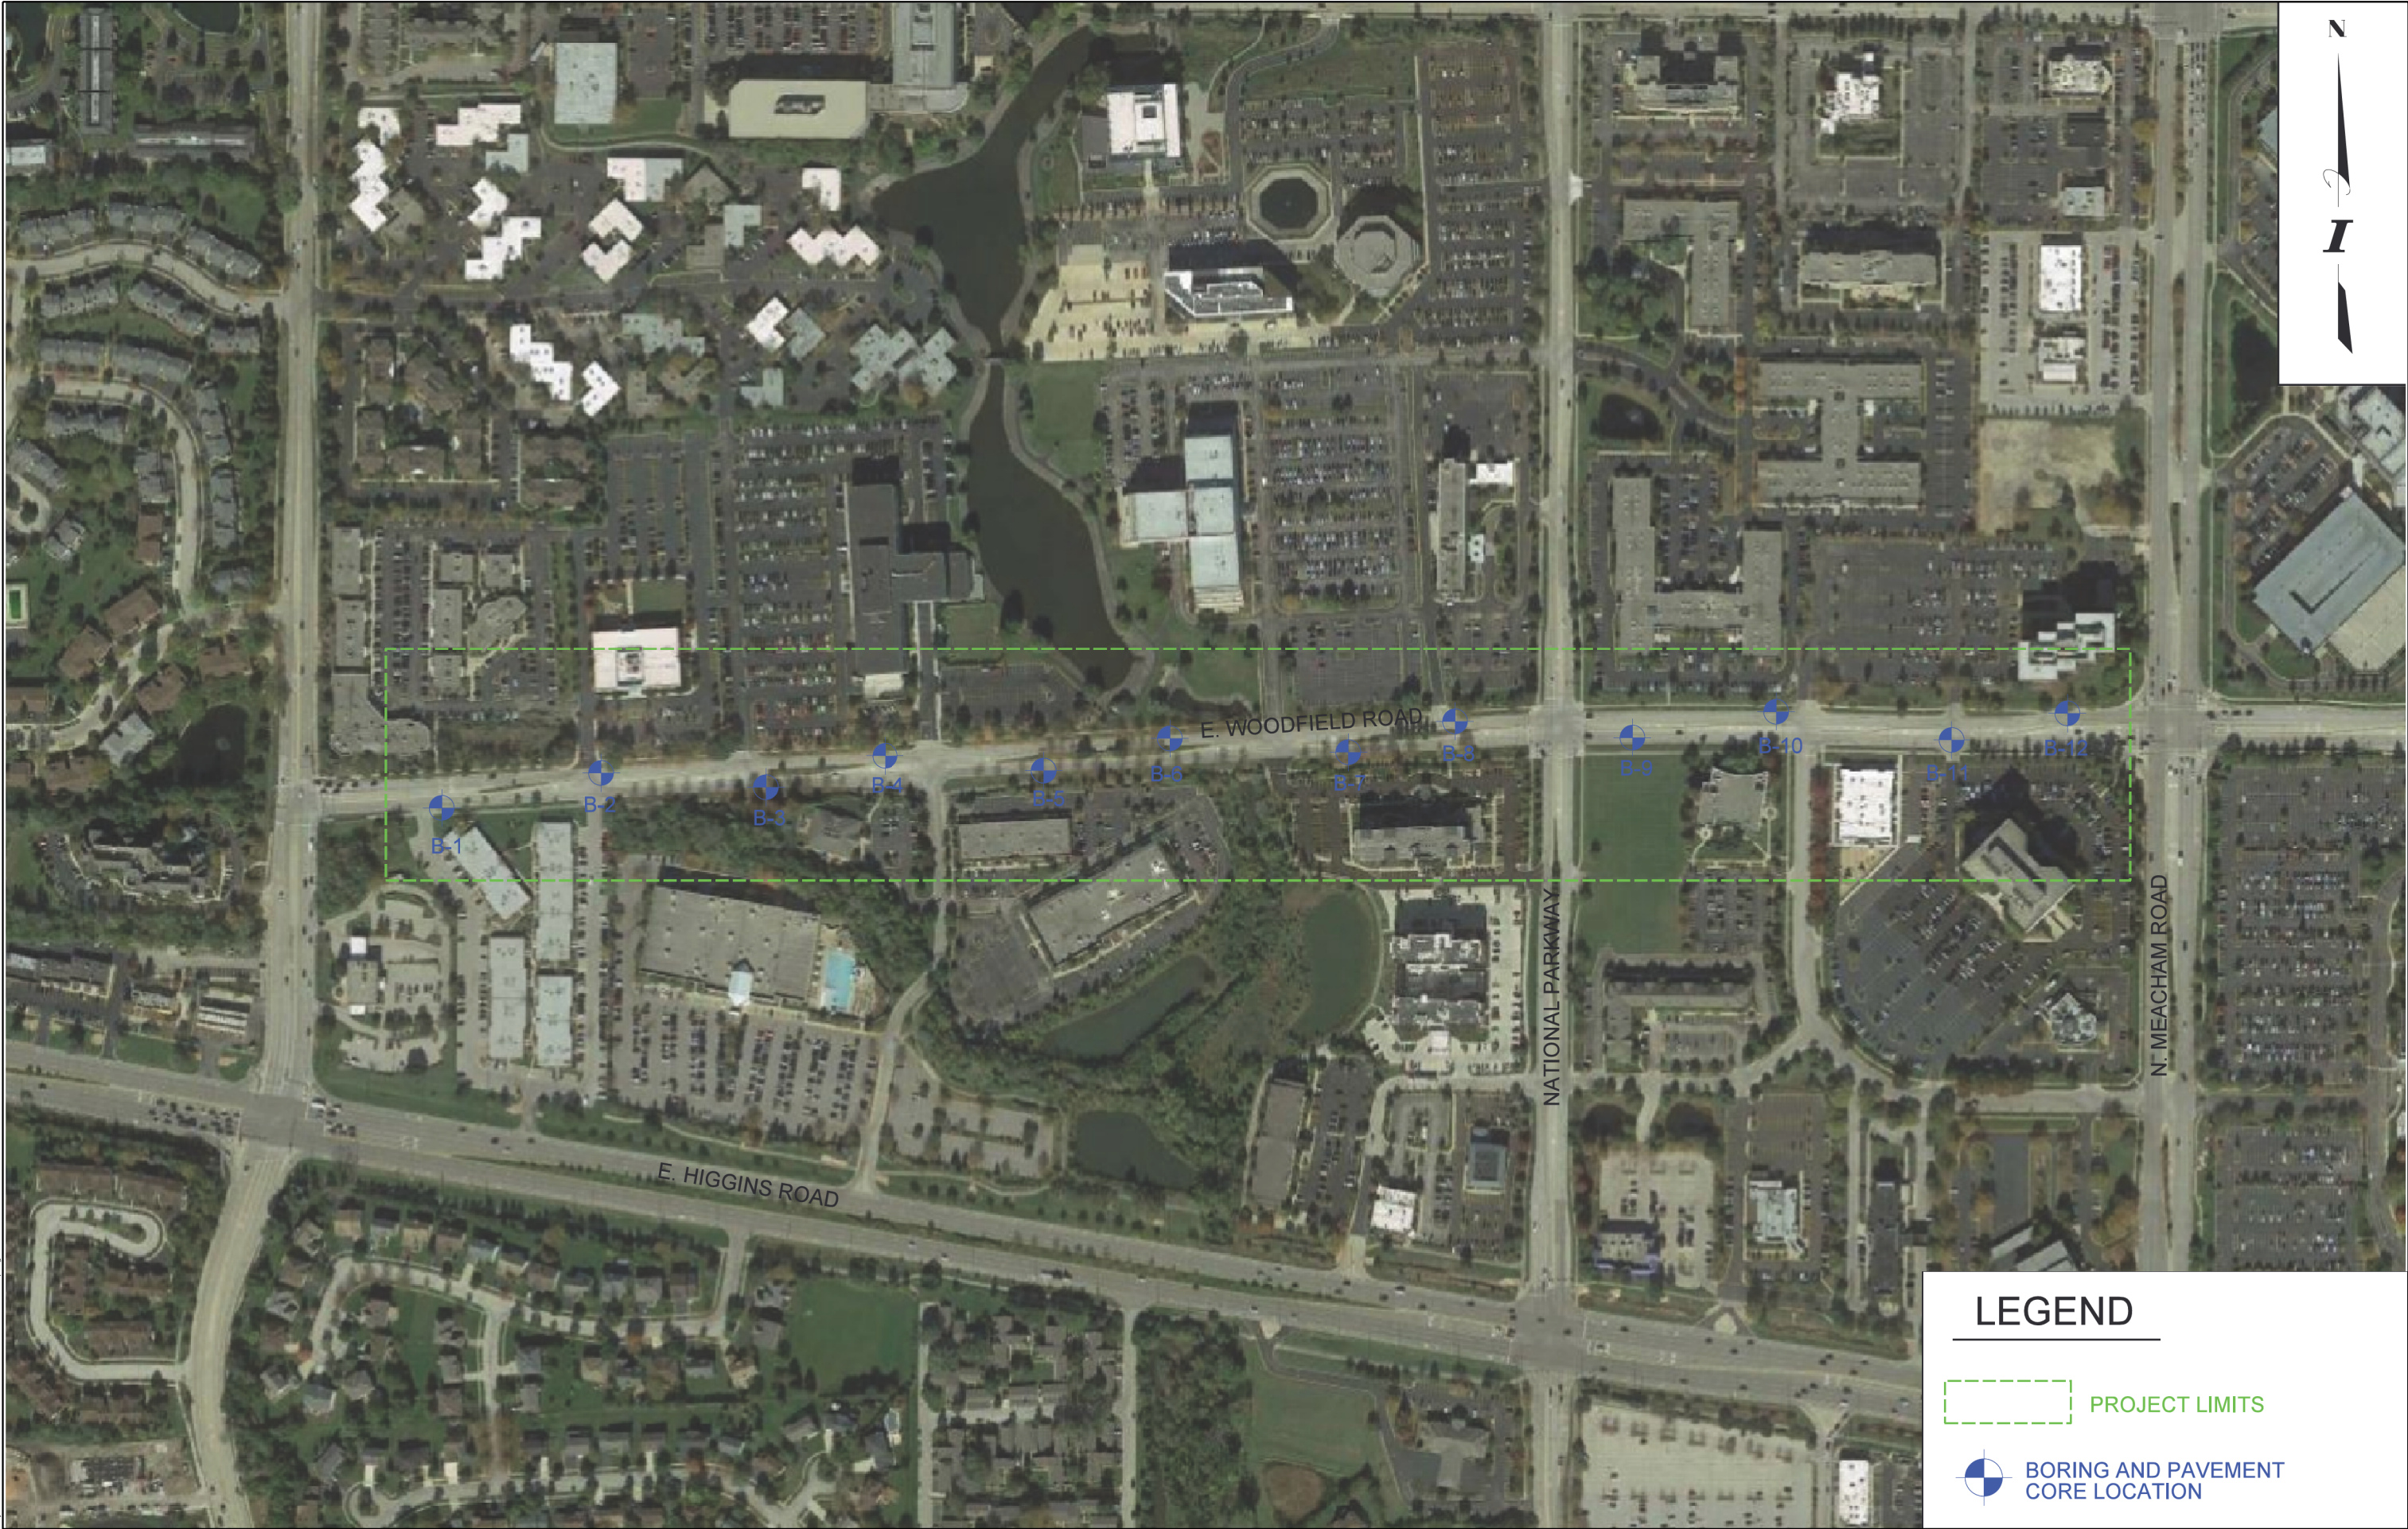


LEGEND

 PROJECT LIMITS

 BORING AND PAVEMENT
CORE LOCATION

	USER NAME = mohammed.ah			DESIGNED - RH	REVISED -	STATE OF ILLINOIS DEPARTMENT OF TRANSPORTATION			WOODFIELD ROAD SOIL BORING LOGS - MAP			F.A.U RTE.	SECTION	COUNTY	TOTAL SHEETS	SHEET NO.
	DRAWN - CW			CHECKED - TDM	REVISED -				SCALE: N/A			3073	20-00134-00-RS	COOK	166	129
	PLOT SCALE = 100,0000' / in.			DATE - 01/11/2025	REVISED -				SHEET 1 OF 6 SHEETS			CONTRACT NO. 61L43				
	PLOT DATE = 9/2/2025								TO STA.			ILLINOIS FED. AID PROJECT				

MODEL Default
FILE NAME: P:\Projects\19014\001\CAD\CADD\Draw Sheets\19014-shl-sol.dgn

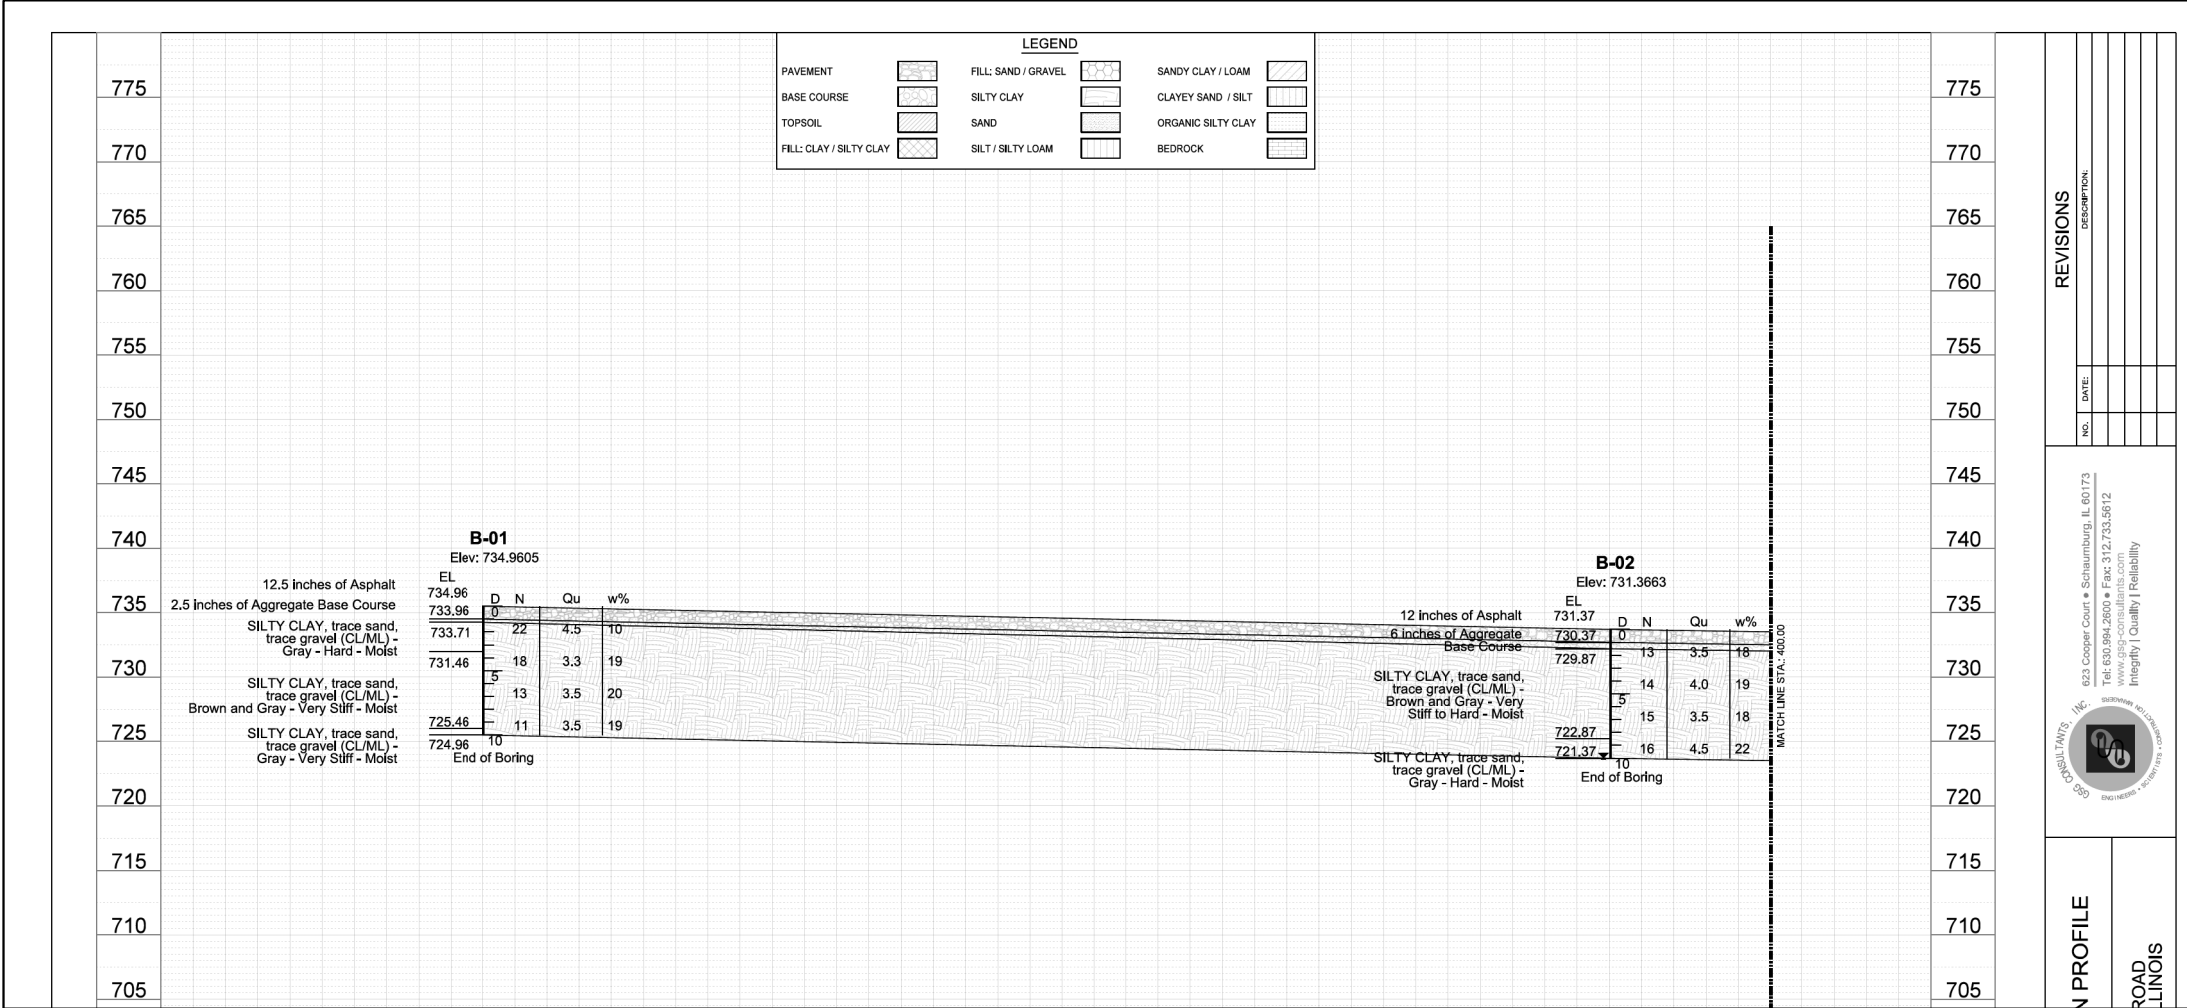

N PROFILE

ROAD
LINOIS


REVISIONS

DESCRIPTION

DATE:

NO.

622 Cooper Court • Schaumburg, IL 60173
Tel: 630.994.2800 • Fax: 312.733.5612
www.sbg-consultants.com
Integrity | Quality | Reliability

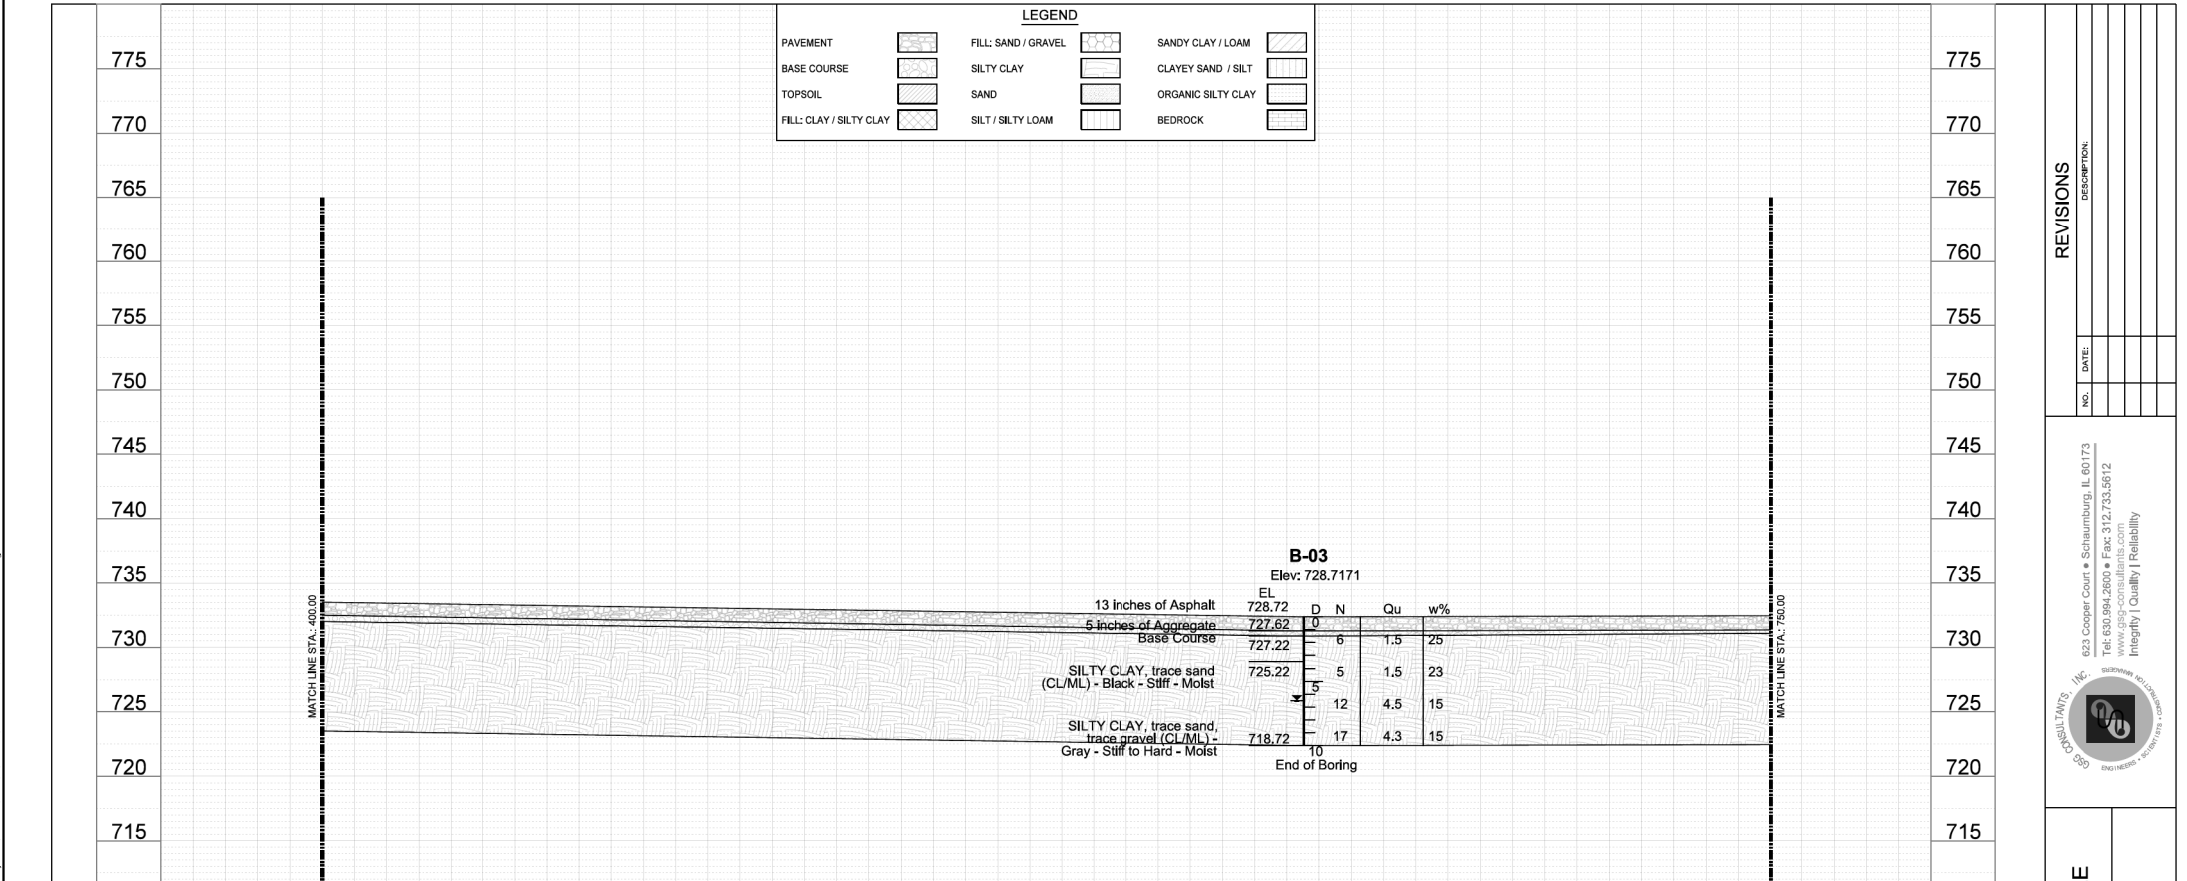

REVISIONS

DESCRIPTION

DATE:

NO.

622 Cooper Court • Schaumburg, IL 60173
Tel: 630.994.2800 • Fax: 312.733.5612
www.sbg-consultants.com
Integrity | Quality | Reliability



U

MODEL: Default
FILE NAME: P:\projects\19014\001\CCADD\CAD Sheets\19014-shc-soll-02.dgn



USER NAME = mohammed.a
PLOT SCALE = 100.0000' / in.
PLOT DATE = 9/2/2025

DESIGNED - RH
DRAWN - CW
CHECKED - TDM
DATE - 01/11/2025


REVISED -
REVISED -
REVISED -
REVISED -

STATE OF ILLINOIS
DEPARTMENT OF TRANSPORTATION

SCALE: N/A
SHEET 3 OF 6 SHEETS
STA. N/A TO STA. N/A

WOODFIELD ROAD
SOIL BORING LOGS - PROFILE

F.A.U RTE.	SECTION	COUNTY	TOTAL SHEETS	SHEET NO.
3073	20-00134-00-RS	COOK	166	131
CONTRACT NO. 61L43				
ILLINOIS FED. AID PROJECT				

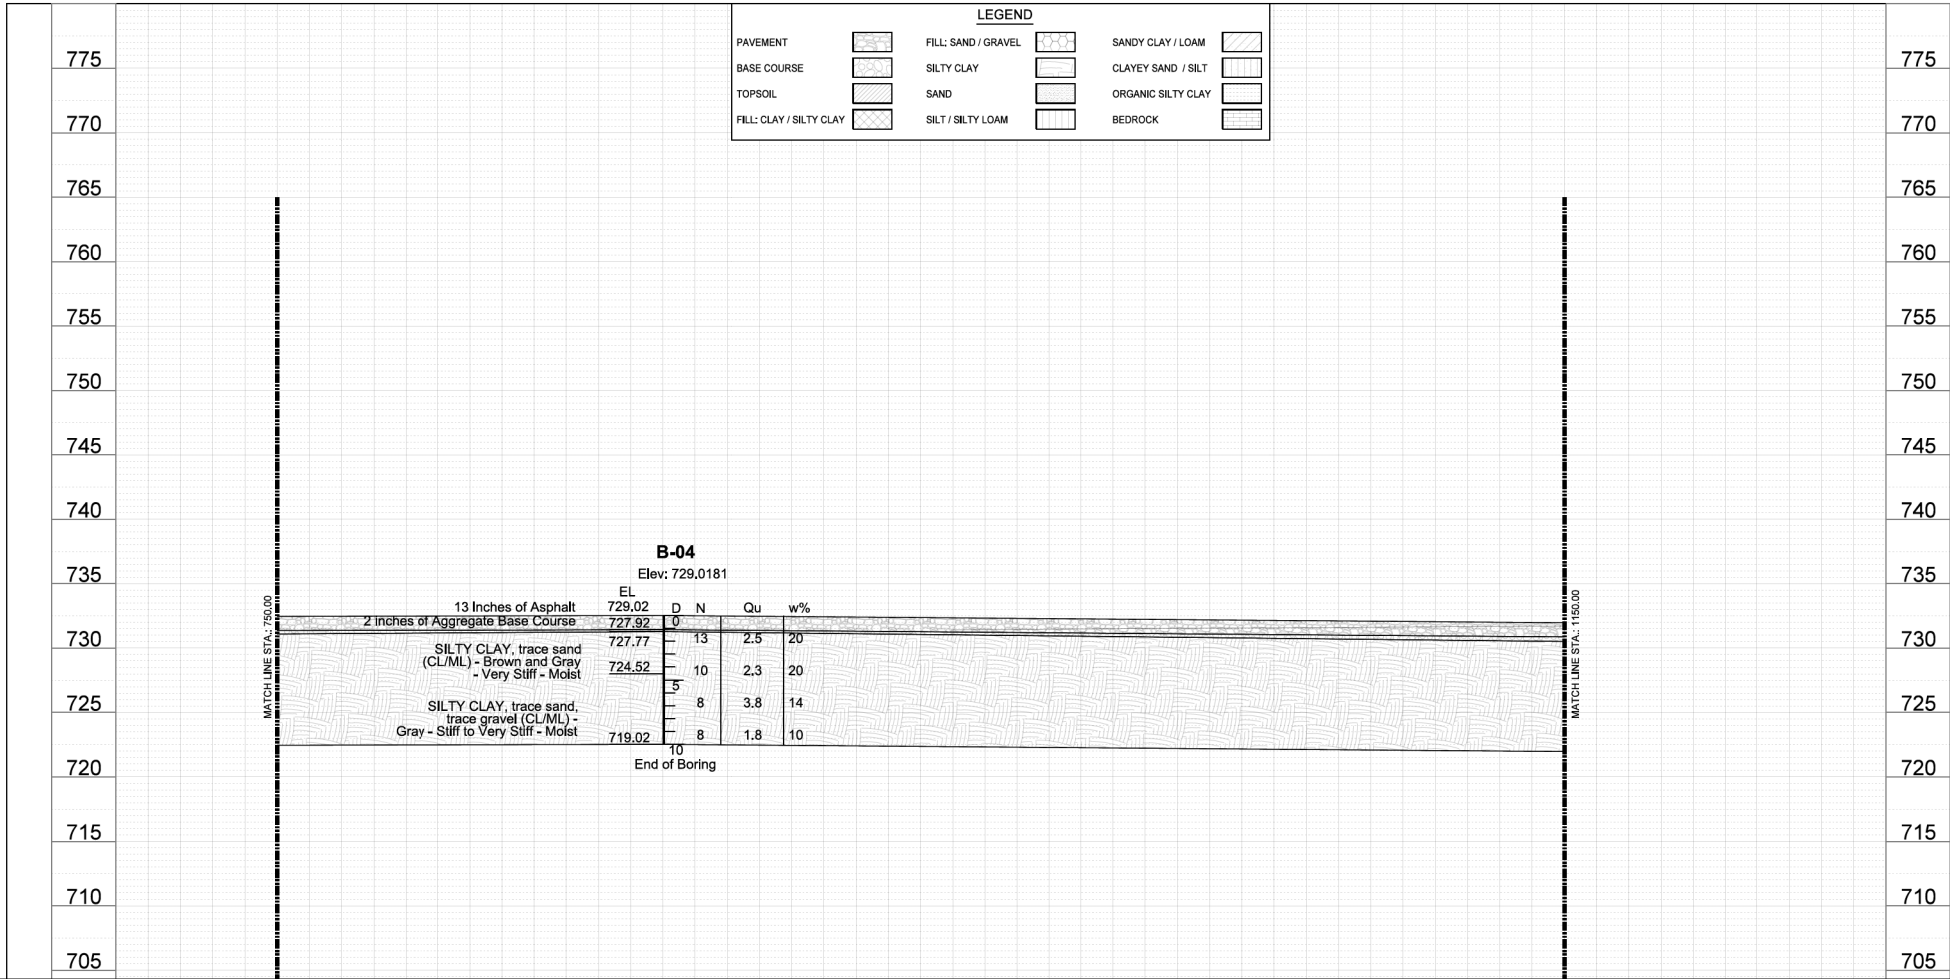


REVISIONS

NO.	DATE	DESCRIPTION

623 Cooper Court • Schaumburg, IL 60173
Tel: 630.994.2800 • Fax: 312.733.5612
www.gig-consultants.com
Integrity | Quality | Reliability

SOIL CONSULTANTS, INC.
ENGINEERS & SURVEYORS

N PROFILE
ROAD
ILINOIS

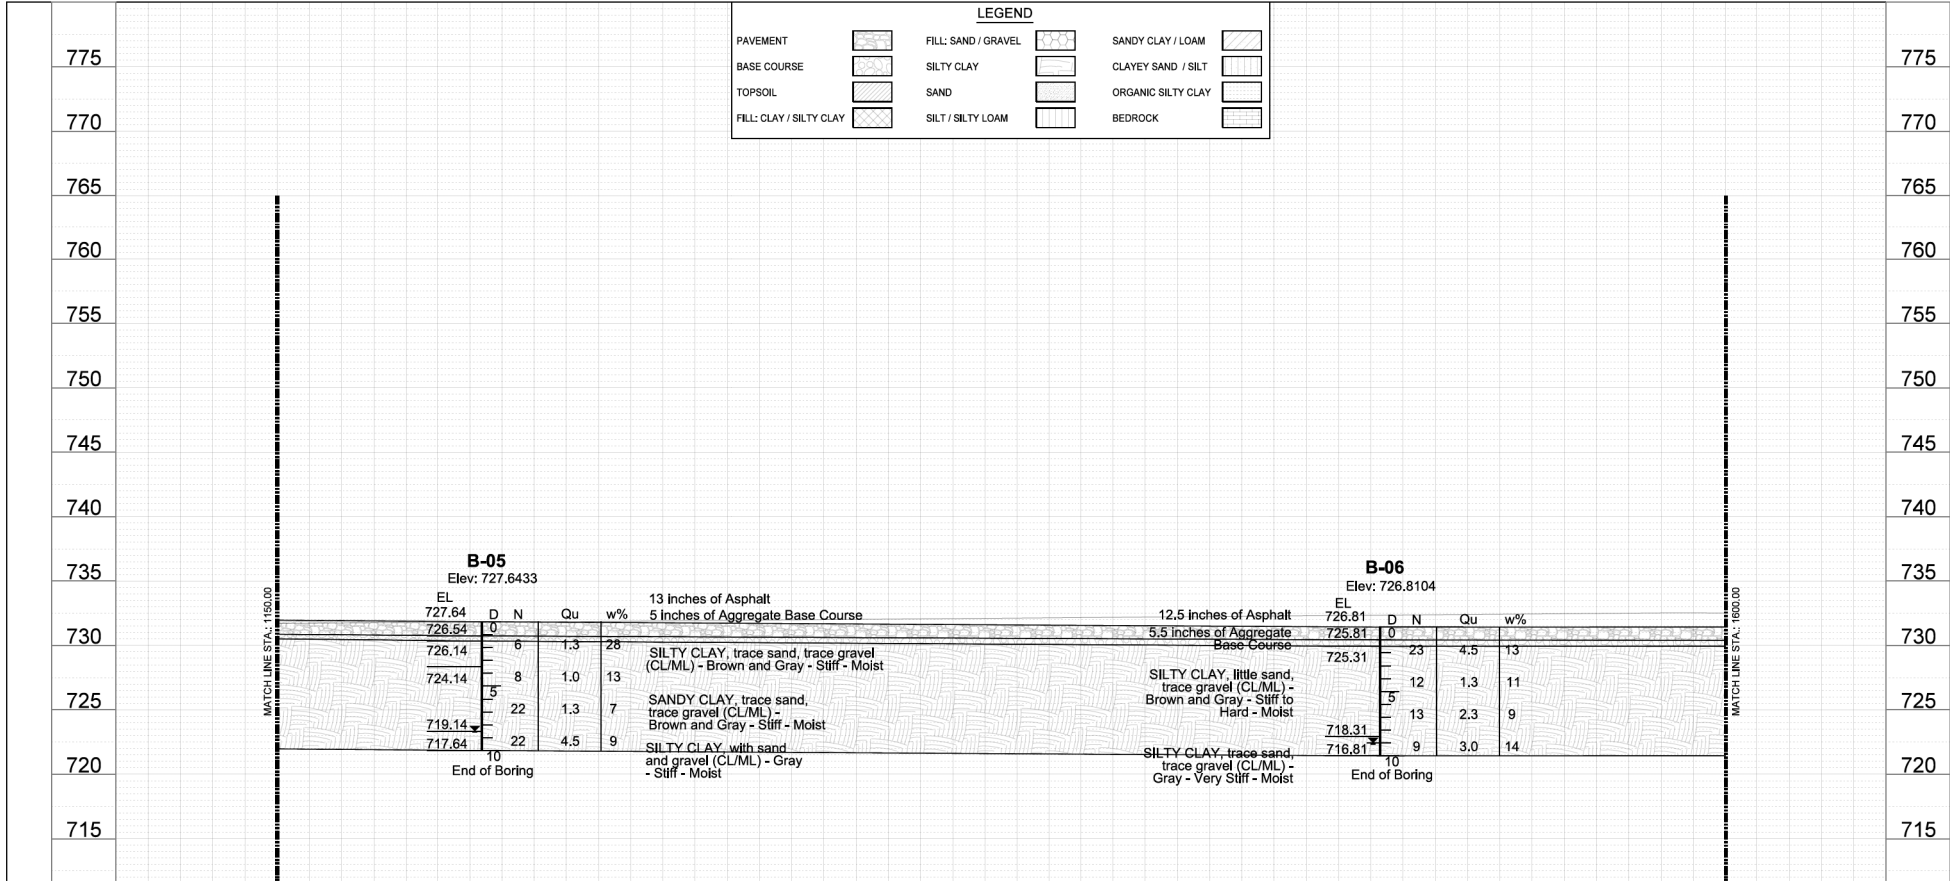

REVISIONS

NO.	DATE	DESCRIPTION

623 Cooper Court • Schaumburg, IL 60173
Tel: 630.994.2800 • Fax: 312.733.5612
www.gig-consultants.com
Integrity | Quality | Reliability

SOIL CONSULTANTS, INC.
ENGINEERS & SURVEYORS

E

R4-7a
24"X30"

KEEP
→
RIGHT

4" YELLOW REFLECTIVE MARKING TAPE (WHITE SKIP-DAS)

ARROW BOARD

L
(SEE NOTE 1)

ONLY

MEDIAN


SEE DETAIL "A"

FIGURE 1

FIGURE 2


	WORK AREA
	LANE OPEN TO TRAFFIC
	ARROW BOARD
	TYPE I OR II BARRICADE OR DRUM WITH STEADY BURN LIGHT
	DRUM WITH STEADY BURN LIGHT
	SIGN ASSEMBLY
	TYPE I OR II CHECK BARRICADE WITH FLASHING LIGHT

1. A) WHEN "L" IS $\leq$ THE STORAGE LENGTH OF THE TURN LANE
(AS SHOWN IN FIG. 1), USE FIGURE 1.
- B) WHEN "L" IS $>$ THE STORAGE LENGTH OF THE TURN LANE
OR THE TURN LANE IS WITHIN THE LANE CLOSURE, USE FIGURE 2.
2. CONES WHEN BE SUBSTITUTED FOR BARRICADES OR DRUMS AT HALF THE
SPACING DURING DAY OPERATIONS. CONES SHALL BE A MINIMUM OF
28 (710) IN HEIGHT.
3. LIGHTS WILL NOT BE REQUIRED ON BARRICADES OR DRUMS FOR DAY
OPERATIONS. ALL LIGHTS SHALL BE MONODIRECTIONAL.
4. REFLECTIVE TEMPORARY PAVEMENT MARKINGS SHALL BE PLACED
THROUGHOUT THE BARRICADED AREAS OF EACH TURN BAY AS SHOWN
WHERE THE CLOSURE TIME IS GREATER THAN FOURTEEN (14) DAYS.
5. THIS APPLICATION ALSO APPLIES WHEN WORK IS BEING PERFORMED IN
THE RIGHT LANE(S) AND THE RIGHT TURN BAY IS TO REMAIN OPEN. UNDER
THIS CONDITION, "RIGHT TURN LANE" R3-1100R 24 x 24 (600 x 600)
AND M6-2R 21 x 15 (530 x 380) SHALL BE USED.
6. THESE CONTROLS SHALL SUPPLEMENT MAINLINE TRAFFIC CONTROL
FOR LANE CLOSURES.
7. THE SIGNS BE MOUNTED ABOVE THE BARRICADES/DRUMS
ON SEPARATE SIGN SUPPORTS THAT MEET NCHRP 350 OR MASH
REQUIREMENTS.
8. TRAFFIC CONTROL AND PROTECTION AT TURN BAYS (TO REMAIN OPEN
TO TRAFFIC) SHALL BE INCLUDED IN THE COST OF SPECIFIED TRAFFIC
CONTROL STANDARDS OR ITEMS.

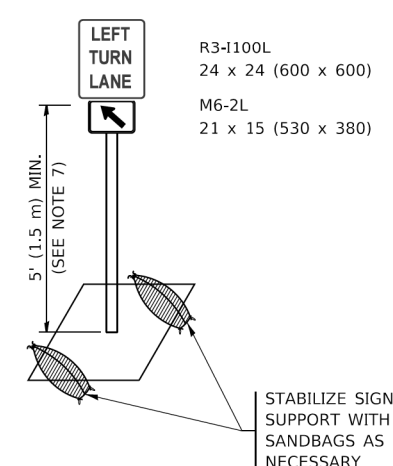

DETAIL A


All dimensions are in inches (millimeters) unless otherwise shown.

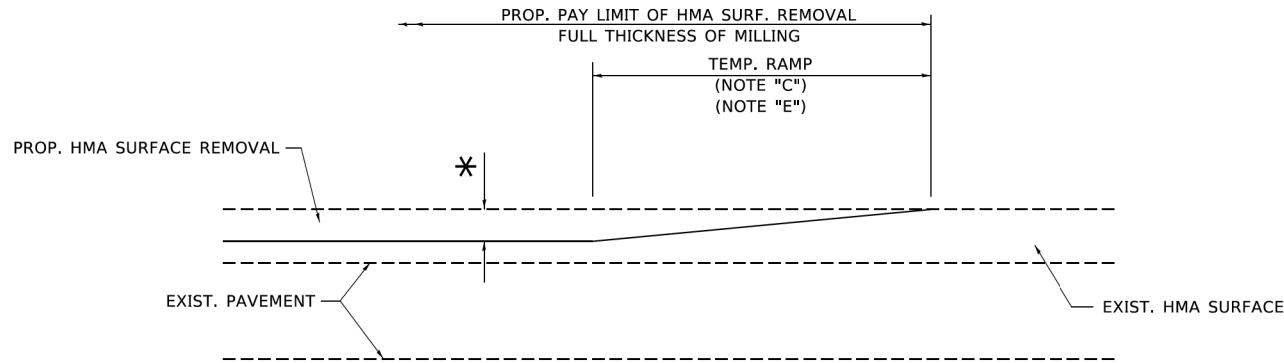

MILLED TEMPORARY RAMP

(FOR BUTT JOINT AND HMA TAPER SEE DETAIL BELOW)

OPTION 1

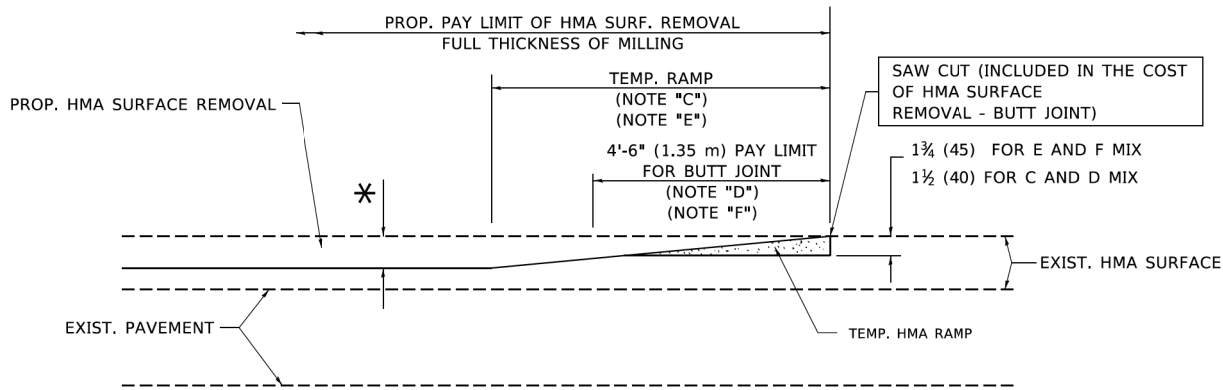


HMA CONSTRUCTED TEMPORARY RAMP

(FOR BUTT JOINT AND HMA TAPER SEE DETAIL BELOW)


OPTION 2

TYPICAL TEMPORARY RAMP

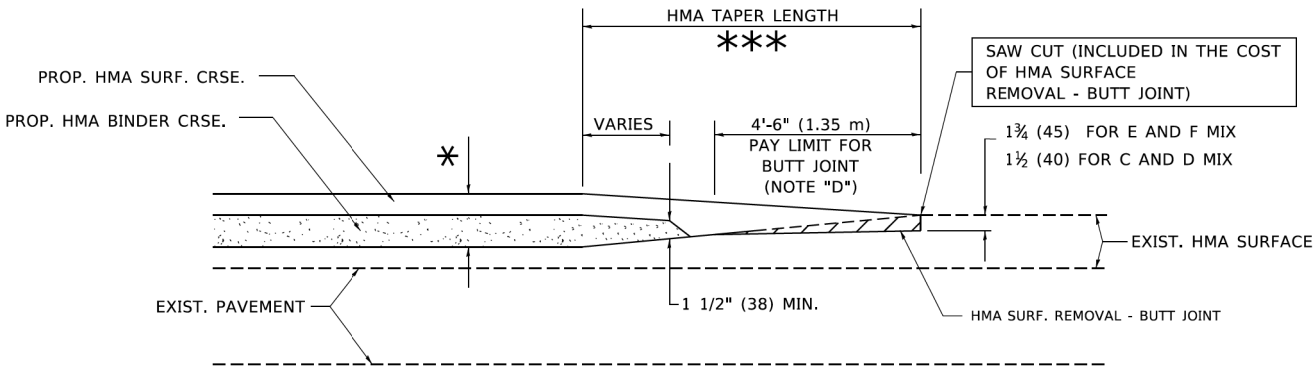


BUTT JOINT AND HMA TAPER

TYPICAL BUTT JOINT AND HMA TAPER FOR MILLING AND RESURFACING

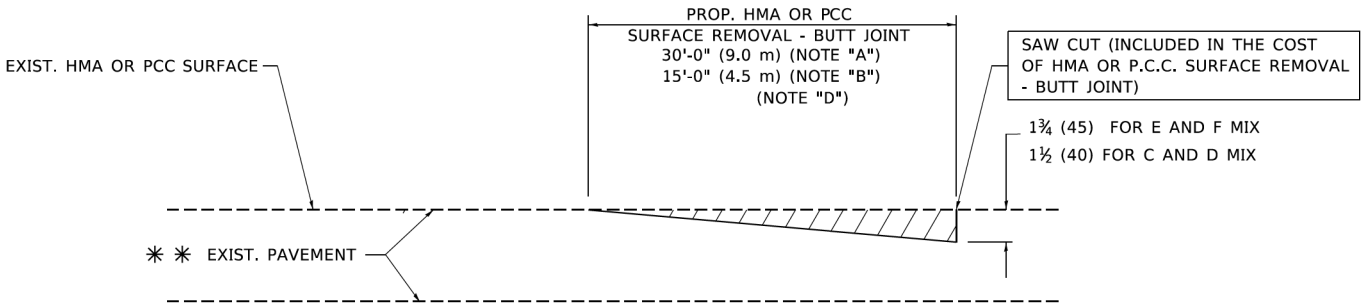

BUTT JOINT DETAIL

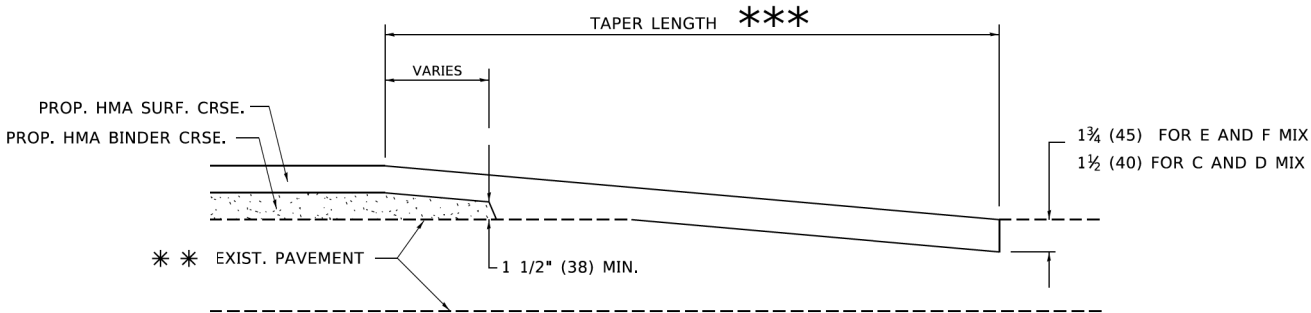

HMA TAPER DETAIL

TYPICAL BUTT JOINT AND HMA TAPER FOR RESURFACING ONLY

** PC CONCRETE, HMA OR HMA RESURFACED PAVEMENT.

NOTES

- A. MAINLINE ROADWAYS AND MAJOR SIDE ROADS.
- B. MINOR SIDE ROADS.
- C. THE TEMP. RAMP SHALL BE CONSTRUCTED IMMEDIATELY UPON REMOVAL OF THE EXISTING HMA SURFACE.
- D. THE BUTT JOINT SHALL BE CONSTRUCTED IMMEDIATELY PRIOR TO PLACING THE PROPOSED HMA COURSES.
- E. TAPER THE TEMP. RAMP AT A RATE OF 3'-0" (900 mm) PER 1 INCH (25 mm) OF MILLING THICKNESS.
- F. INSTALLATION AND REMOVAL OF THE 4'-6" (1.35 m) TEMP. RAMP IS INCLUDED IN COST OF HMA SURFACE REMOVAL - BUTT JOINT.
* SEE TYPICAL SECTIONS FOR MILLING THICKNESS.
- G. SEE ARTICLE 406.08 AND 406.14 OF THE STANDARD SPECIFICATIONS FOR "HMA AND/OR PCC SURFACE REMOVAL, BUTT JOINT".
*** 20'-0" (6.1 m) PER 1 (25) RESURFACING (NOTE "A")
10'-0" (3.0 m) PER 1 (25) RESURFACING (NOTE "B")

BASIS OF PAYMENT

THE BUTT JOINT WILL BE PAID FOR AT THE CONTRACT UNIT PRICE PER SQUARE YARD (SQUARE METER) FOR "HOT-MIX ASPHALT SURFACE REMOVAL - BUTT JOINT" OR FOR "PORTLAND CEMENT CONCRETE SURFACE REMOVAL- BUTT JOINT".

ALL DIMENSIONS ARE IN INCHES (MILLIMETERS) UNLESS OTHERWISE SHOWN.

MODEL: Default
FILE: D:\Users\p31001\OneDrive\Projects\1901\1001\CCADD\CAD Sheets\1901-14-Sub-Standard.dgn




USER NAME = mohammed.ait	DESIGNED - RH	REVISED -
	DRAWN - CW	REVISED -
PLOT SCALE = 100.0000 ' / in.	CHECKED - TDM	REVISED -
PLOT DATE = 9/2/2025	DATE - 01/11/2025	REVISED -


STATE OF ILLINOIS
DEPARTMENT OF TRANSPORTATION

WOODFIELD ROAD
HIGHWAY STANDARDS – BUTT JOINT AND HMA TAPER DETAILS

SCALE: N/A SHEET 9 OF 16 SHEETS STA. N/A TO STA. N/A


F.A.U RTE.	SECTION	COUNTY	TOTAL SHEETS	SHEET NO.
3073	20-00134-00-RS	COOK	166	143
BD-32		CONTRACT NO. 61L43		
		ILLINOIS	FED. AID PROJECT	

 

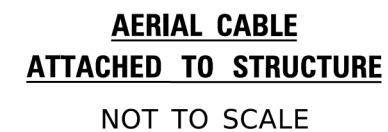


1. ALL DIMENSIONS IN INCHES (MILLIMETERS)
UNLESS OTHERWISE INDICATED.
2. SEE PROPOSED LIGHTING PLAN FOR CONDUIT, CABLE
AND ROUTING.
3. THE CONTRACTOR SHALL PROVIDE INTERMEDIATE SUPPORTS
TO MAINTAIN MINIMUM CLEARANCES. REFER TO AERIAL
AERIAL CABLE ATTACHED TO STRUCTURE DETAIL.
4. COST OF SPLICES AND MOUNTING HARDWARE SHALL BE
INCLUDED IN THE UNIT PRICE FOR AERIAL CABLE.


MODEL: Default
FILE: luminaire_1300134-00-001.dwg
PROJECT: 1300134-00-001.dwg
SHEET: 1300134-00-001.dwg
SHEET: 1300134-00-001.dwg

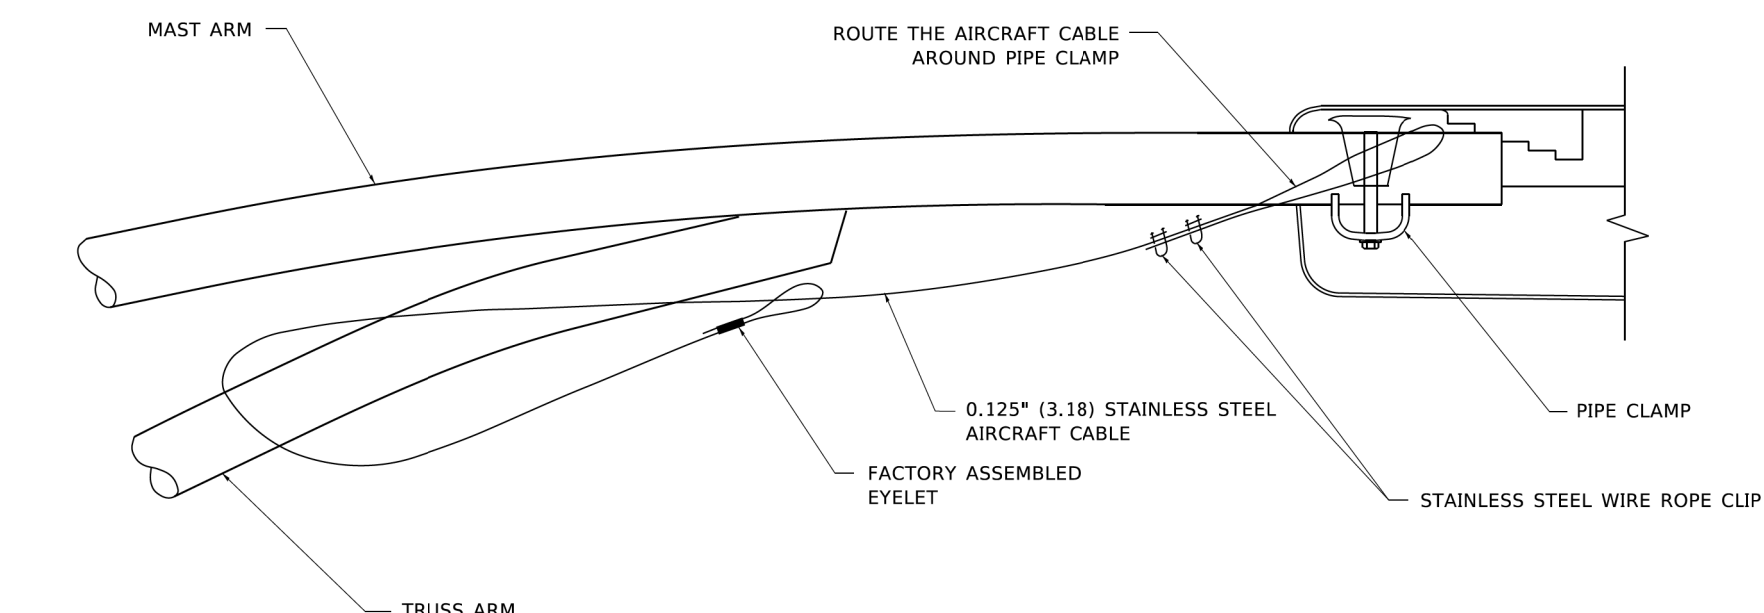

SIDE VIEW (TRUSS ARM)
N.T.S.

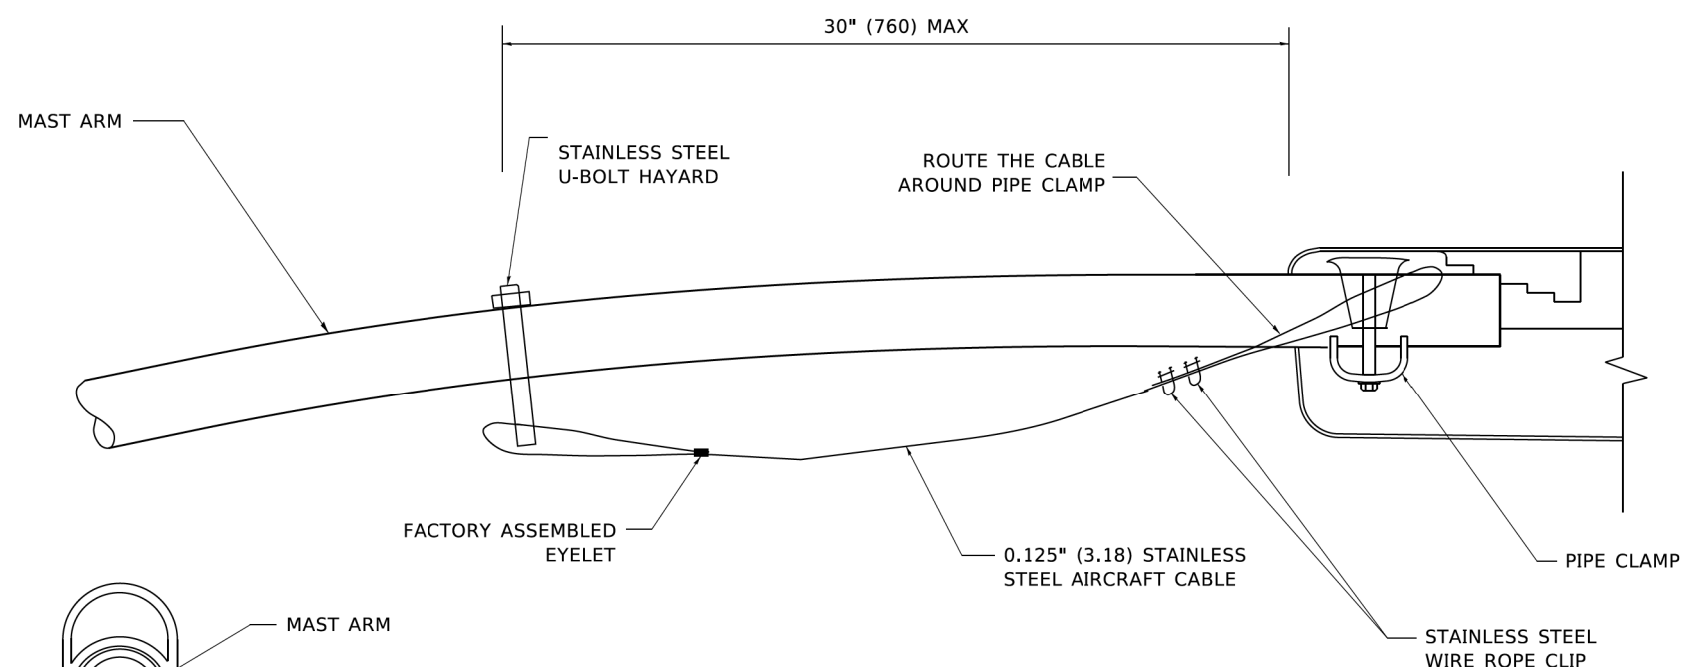


SIDE VIEW (SINGLE MEMBER OR DAVIT ARM)
N.T.S.

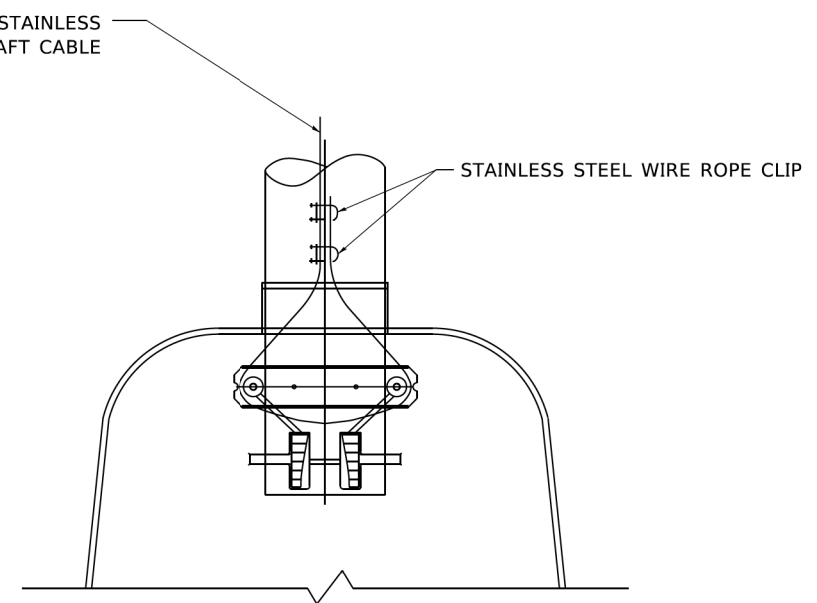

BOTTOM VIEW
N.T.S.


- NOTES:**
1. ALL DIMENSIONS ARE IN MILLIMETERS (INCHES) UNLESS OTHERWISE SHOWN.
 2. CONTRACTOR SHALL ADJUST THE WIRE CLIP TO ELIMINATE ANY SLACK FROM THE WIRE ROPE.
 3. THE 0.125\" (3.18) STAINLESS STEEL AIRCRAFT CABLE SHALL REMAIN VISIBLE FROM THE GROUND LEVEL.
 4. THE BREAKING STRENGTH OF THE CABLE SHALL BE 1700 LBS. MIN.

PROVIDE A PAVEMENT REPLACEMENT
NOTE WHICH SHOULD EQUAL
3' (900 mm) X WIDTH OF
PAVED SHOULDER.

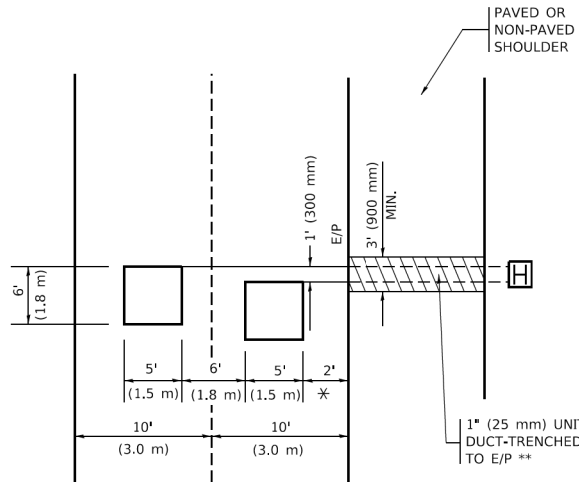


* * UNIT DUCT IS TO BE SHOWN ON PLAN SHEETS
BUT SHALL NOT BE INCLUDED IN THE PAY ITEMS.

HANDHOLE LOCATION MAY VARY DEPENDING ON GEOMETRICS AND DESIGN OF TRAFFIC SIGNALS. HEAVY-DUTY HANDHOLES TO BE USED WHEN THE MEDIAN IS MOUNTABLE. REFER TO STANDARD 814001 TO ENSURE THAT HANDHOLE FITS IN MEDIAN.

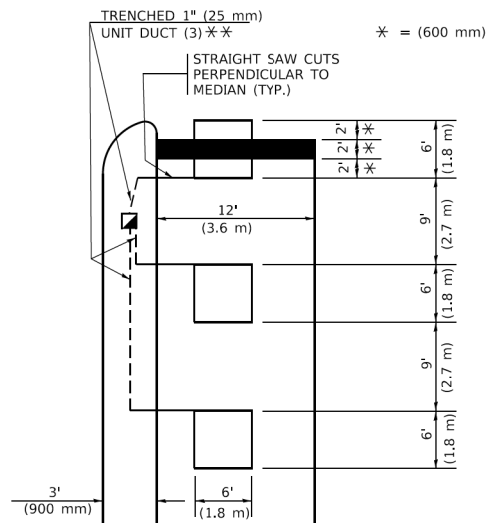

NOTE: DUAL LEFT TURNS NOT SHOWN REFER TO
PLAN SHEET FOR DETECTOR LOOP REPLACEMENT

VOLUME DENSITY ("FAR OUT" DETECTION)
ON SAME APPROACH

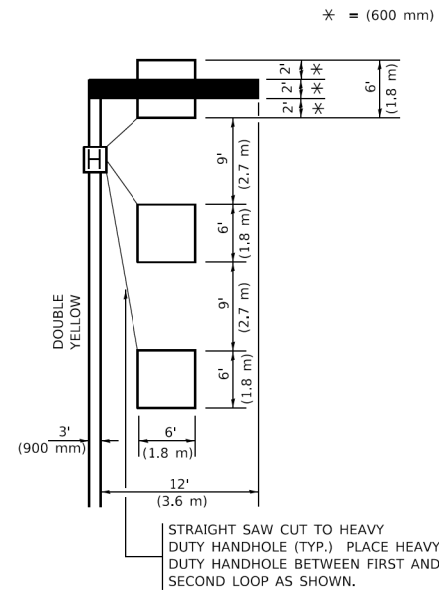

NOTES:

* ALL LEAD IN CABLE SHALL BE TWO CONDUCTOR NO. 14 TWISTED, SHIELDED.

* EACH DETECTOR LOOP SHALL HAVE ITS OWN SAW CUT FROM THE LOOP TO THE EDGE OF PAVEMENT OR TO A HANDHOLE IN THE PAVEMENT.

* EACH DETECTOR LOOP SHALL HAVE ITS OWN ONE INCH (25 mm) UNIT DUCT BETWEEN THE EDGE OF PAVEMENT AND THE FIRST HANDHOLE OR JUNCTION BOX. EACH UNIT DUCT RUN SHALL BE SHOWN ON THE PLANS BY THE DESIGNER, BUT SHALL NOT BE PAID FOR SEPARATELY. THIS ITEM IS INCIDENTAL TO THE PAY ITEM FOR DETECTOR LOOPS.

* ONE DIMENSION OF ALL DETECTOR LOOPS SHALL BE SIX FEET (1.8 m)

* EACH LANE OF NON-LOCKING, PRESENCE DETECTION AND EACH LANE OF A DOUBLE LEFT TURN LANE REQUIRES A SEPARATE INDUCTIVE LOOP DETECTOR AND LEAD IN CABLE.

* WHEN NON-LOCKING, PRESENCE DETECTION IS USED, MORE THAN ONE LOOP PER LANE IS REQUIRED BEHIND THE STOP BAR (i.e. 1-1/2, 1-3/4, 2).

* WHEN SYSTEM LOOPS ARE REQUIRED ON AN APPROACH OF AN INTERSECTION, THE LOOPS USED FOR VOLUME DENSITY AND INTERSECTION TIMING SHALL ALSO BE USED AS SYSTEM DETECTORS. EACH ONE OF THESE TYPE OF LOOPS REQUIRES A SEPARATE TWO CONDUCTOR NO. 14 TWISTED SHIELDED CABLE AND A SEPARATE INDUCTIVE LOOP DETECTOR WHEN NEW CONTROLLERS ARE UTILIZED. THE DESIGNER SHALL LABEL THESE TYPES OF LOOPS AS "INTERSECTION AND SAMPLING (SYSTEM) DETECTORS" ON THE SIGNAL LAYOUT, THE INTERCONNECT PLAN AND THE SYSTEM CABLE PLAN. WHEN AN EXISTING CONTROLLER IS UTILIZED FOR THIS TYPE OF DETECTION, THE PAY ITEM "INDUCTIVE LOOP DETECTOR WITH SYSTEM OUTPUT" SHOULD BE USED.

Figure 10: Typical Callout Loop Locations. The diagram shows three scenarios of loop placement:

- Top View:** Shows a cross street intersecting an arterial road. Loops are placed at the curb line, with dimensions of 11' (3.3m) and 2' (600mm) from the curb. A note states: "DO NOT INSTALL CALLING LOOP IN RIGHT TURN LANE." and "10' (3.0m) OR CLOSER DEPENDING ON DRIVEWAY LOCATION.".
- Side View (Left):** Shows a driveway intersection with a cross street. Dimensions include 10' (3.0m) and 2' (600mm) from the curb. A note indicates: "CALLING LOOPS".
- Side View (Right):** Shows a driveway intersection with a cross street. Dimensions include 12' (3.6m) and 2' (600mm) from the curb. A note indicates: "TYP.-12' (3.6m) LANES".

Additional notes and dimensions include:

- "STRAIGHT SAW CUTS TO HEAVY-DUTY HANDHOLE IN PAVEMENT (TYP.)"
- "TYP.-ALL LEGS-VOL DENSITY" (250' (75m))
- "OFF SET LOOPS 6' (1.8m) OR 1' (300mm) FOR STRAIGHT SAW CUTS"
- Legend: * = (1.8m), *6' = (1.5m)

LOOPS ARE SAW-CUT
TO THE EDGE OF
PAVEMENT. 1" (25 mm)
DUCT IS RUN BETWEEN
EDGE OF PAVEMENT
AND HANDHOLE.
(TYP. FOR LOOPS
THAT TERMINATE
IN HANDHOLES
OUTSIDE PAVEMENT)

[illegible]

Diagram 100-100-01: Typical Right Turn Lane

Diagram illustrating the typical dimensions for a Right Turn Lane at an intersection.

Key dimensions and components shown:

- Offset loops by 1' (300mm) for straight saw cuts.
- THIS DIMENSION MAY BE ADJUSTED FOR DRIVEWAY OR OTHER OBSTRUCTIONS. WHEN ADJUSTMENT IS REQUIRED, DETECTORS WILL NORMALLY BE MOVED CLOSER TO THE INTERSECTION.
- * = (1.8m)
- CROSS STREET
- ARTERIAL
- 3' (900mm)
- 1" (25 mm) UNIT DUCT (TYP.)
- 3' (900mm)
- 12' (3.6m)
- 9' (2.7m)
- 10' (3.0m) PREFERRED
- 15' (4.5m) MAXIMUM
- 3' (900mm)
- 6' (1.8m) MINIMUM, 25' (7.6 m) MAXIMUM
- 5' (1.5m) for 10' (3.0m) LANE WIDTHS
- DRIVEWAY
- IF "FAR OUT" LOOPS ARE LOCATED IN TAPER OF A RIGHT TURN LANE, DIMENSION THIS LOOP TO TAPER AREA.

- + - THESE DIMENSIONS
WILL BE VARIABLE
[6' (1.8m) MINIMUM,
25' (7.6 m) MAXIMUM]
- Δ - THESE DIMENSIONS
SHALL BE 5' (1.5m) FOR
10' (3.0m) LANE WIDTH

IF "FAR OUT" LOOPS ARE LOCATED IN TAPER OF A RIGHT TURN LANE, DIMENSION THIS LOOP TO COVER TAPER AREA. DO NOT COVER THE LEFT TURN LANE OR LEFT TURN LANE TAPER.

MODEL Default
FILE Name: P:\Projects\19014\001\CCADD\CAD Sheets\19014-sh-Stdns.docx



USER NAME = mohammed.ah	DESIGNED - RH	REVISED -
	DRAWN - CW	REVISED -
PLOT SCALE = 100,0000 ' / in.	CHECKED - TDM	REVISED -
PLOT DATE = 9/2/2025	DATE - 01/11/2025	REVISED -

STATE OF ILLINOIS
DEPARTMENT OF TRANSPORTATION

WOODFIELD ROAD HIGHWAY STANDARDS - EMERGENCY VEHICLE PREEMPTION - SEQUENCE OF OPERATION			
SCALE: N/A	SHEET 15	OF 16 SHEETS	STA. N/A TO STA. N/A

F.A.U RTE.	SECTION	COUNTY	TOTAL SHEETS	SHEET NO.
3073	20-00134-00-RS	COOK	166	149
TS-08		CONTRACT NO. 61L43		
		ILLINOIS	FED. AID PROJECT	

EMERGENCY VEHICLE PREEMPTION SEQUENCE OF OPERATION

EMERGENCY VEHICLE PREEMPTION SEQUENCE OF OPERATION																													PREEMPTOR NUMBER 3		PREEMPTOR NUMBER 4		CLEAR TO NORMAL SEQUENCE
CHANGE FROM NORMAL SEQUENCE OF OPERATION INTERVAL NUMBER	1	5			5			8		8			11	11			14	18			18		22			22		26			26		
EMERGENCY VEHICLE PREEMPTION SEQUENCE OF OPERATION INTERVAL NUMBER	1A	1B	1C	1D	1E	1F	1G	1H	1J	1K	1L	1M	1N	1P	1Q	1R	1S	1T	1U	1V	1W	1X	1Y	1Z	1AA	1BB	1CC	1DD	1EE	1FF	2	3	
CHANGE TO EMERGENCY VEHICLE PREEMPTION SEQUENCE OF OPERATION INTERVAL NUMBER	2 OR 3	1C	2	1E	1F	3	1H	2	1K	1L	3	2	1P	1Q	3	2 OR 3	1T	1U	2	1W	3	1Y	1Z	2	1BB	3	1DD	1EE	2	3			◇
MAIN STREET END MAST ARM AND FAR LEFT SIGNALS	E/B ←Y	R	R	R	R	R	G ←G	G ←Y	G ←G	Y	R	G	G	Y	R	R	R	R	R	R	R	R	R	R	R	R	R	R	R	R	G	R	◇
MAIN STREET FAR RIGHT SIGNAL	E/B	R	R	R	R	R	R	G	G	G	Y	R	G	G	Y	R	R	R	R	R	R	R	R	R	R	R	R	R	R	R	G	R	◇
MAIN STREET END MAST ARM AND FAR LEFT SIGNALS	W/B ←Y	G ←G	G ←Y	G ←G	Y	R	R	R	R	R	R	G	G	Y	R	R	R	R	R	R	R	R	R	R	R	R	R	R	R	R	G	R	◇
MAIN STREET FAR RIGHT SIGNAL	W/B	R	G	G	G	Y	R	R	R	R	R	G	G	Y	R	R	R	R	R	R	R	R	R	R	R	R	R	R	R	R	G	R	◇
CROSS STREET END MAST ARM AND FAR LEFT SIGNALS	S/B	R	R	R	R	R	R	R	R	R	R	R	R	R	R	R ←Y	R	R	R	R	R	G ←G	Y	R	G ←G	G ←Y	G	Y	R	G	R	G	◇
CROSS STREET FAR RIGHT SIGNAL	S/B	R	R	R	R	R	R	R	R	R	R	R	R	R	R	R	R	R	R	R	G	Y	R	G	G	G	Y	R	G	R	G	◇	
CROSS STREET END MAST ARM AND FAR LEFT SIGNALS	N/B	R	R	R	R	R	R	R	R	R	R	R	R	R	R	R ←Y	G ←G	Y	R	G ←G	G ←Y	R	R	R	R	R	G	Y	R	G	R	G	◇
CROSS STREET FAR RIGHT SIGNAL	N/B	R	R	R	R	R	R	R	R	R	R	R	R	R	R	R	G	Y	R	G	G	R	R	R	R	R	G	Y	R	G	R	G	◇
PEDESTRIAN SIGNALS CROSSING CROSS STREET ON NORTHSIDE OF MAIN STREET	H	FH	H	FH	H	H	H	H	H	H	H	FH	FH	H	H	H	H	H	H	H	H	H	H	H	H	H	H	H	H	H	H	H	◇
PEDESTRIAN SIGNALS CROSSING CROSS STREET ON SOUTHSIDE OF MAIN STREET	H	H	H	H	H	H	FH	H	FH	H	H	FH	FH	H	H	H	H	H	H	H	H	H	H	H	H	H	H	H	H	H	H	H	◇
PEDESTRIAN SIGNALS CROSSING MAIN STREET ON EASTSIDE OF CROSS STREET	H	H	H	H	H	H	H	H	H	H	H	H	H	H	H	H	FH	H	H	FH	H	H	H	H	H	H	FH	H	H	FH	H	H	◇
PEDESTRIAN SIGNALS CROSSING MAIN STREET ON WESTSIDE OF CROSS STREET	H	H	H	H	H	H	H	H	H	H	H	H	H	H	H	H	H	H	H	H	H	FH	H	H	FH	H	FH	H	H	FH	H	H	◇

◇ EMERGENCY VEHICLE SEQUENCE SHALL PROVIDE THE PROPER CLEARANCE
INTERVAL TO RESUME THE NORMAL SEQUENCE OF OPERATION OR PROPER
CLEARANCE INTERVAL TO DISPLAY A DIFFERENT EMERGENCY INTERVAL
AFTER EMERGENCY VEHICLE 2 OR 3 IS TERMINATED.

PROPOSED SEQUENCE OF OPERATION

MOVEMENT																									F L A S H									
PHASE	1 + 5				1 + 6			2 + 5		2 + 6		3 + 7				3 + 8				4 + 7				4 + 8										
INTERVAL	1	2	3	4	5	6	7	8	9	10	11	12	13A	13B	14	15	16	17	18	19	20A	20B	21	22		23	24A	24B	25	26	27	28A	28B	
CHANGE TO		1+6	2+5	2+6			2+6			2+6			3+7 3+8 4+7 4+8		1+5 1+6 2+5 2+6 4+8	3+8	4+7			1+5 1+6 2+5 2+6	4+8			1+5 1+6 2+5 2+6		4+8			1+5 1+6 2+5 2+6	4+8			1+5 1+6 2+5 2+6	
MAIN STREET END MAST ARM AND FAR LEFT SIGNALS	R ←G	R ←Y	R ←G	R ←Y	R	R	R	R ←G	R ←G	R ←Y	G	G	Y	R	R	R	R	R	R	R	R	R	R	R		R	R	R	R	R	R	R	R	
MAIN STREET FAR RIGHT SIGNAL	R	R	R	R	R	R	R	G	G	G	G	G	Y	R	R	R	R	R	R	R	R	R	R	R	R	R	R	R	R	R	R	R		
MAIN STREET END MAST ARM AND FAR LEFT SIGNALS	R ←G	R ←G	R ←Y	R ←Y	R ←G	R ←G	R ←Y	R	R	R	G	G	Y	R	R	R	R	R	R	R	R	R	R	R	R	R	R	R	R	R	R	R		
MAIN STREET FAR RIGHT SIGNAL	R	R	R	R	G	G	G	R	R	R	G	G	Y	R	R	R	R	R	R	R	R	R	R	R	R	R	R	R	R	R	R	R		
CROSS STREET END MAST ARM AND FAR LEFT SIGNALS	R	R	R	R	R	R	R	R	R	R	R	R	R	R	R ←G	R ←Y	R ←Y	R ←G	R	R	R	R	R	R	R ←G	R ←G	Y	R	R ←Y	G	G	Y	R	R
CROSS STREET FAR RIGHT SIGNAL	R	R	R	R	R	R	R	R	R	R	R	R	R	R	R	R	R	R	R	R	R	R	R	G	G	Y	R	G	G	G	Y	R	R	
CROSS STREET END MAST ARM AND FAR LEFT SIGNALS	R	R	R	R	R	R	R	R	R	R	R	R	R	R	R ←G	R ←Y	R ←G	R ←Y	R ←G	R ←G	Y	R	R ←Y	R	R	R	R	R	R	G	G	Y	R	R
CROSS STREET FAR RIGHT SIGNAL	R	R	R	R	R	R	R	R	R	R	R	R	R	R	R	R	R	R	G	G	Y	R	G	R	R	R	R	R	G	G	Y	R	R	
PEDESTRIAN SIGNALS CROSSING CROSS STREET ON NORTHSIDE OF MAIN STREET	H	H	H	H	*P	**FH	H	H	H	H	*P	**FH	H	H	H	H	H	H	H	H	H	H	H	H	H	H	H	H	H	H	H	H	H	
PEDESTRIAN SIGNALS CROSSING CROSS STREET ON SOUTHSIDE OF MAIN STREET	H	H	H	H	H	H	H	*P	**FH	H	*P	**FH	H	H	H	H	H	H	H	H	H	H	H	H	H	H	H	H	H	H	H	H	H	
PEDESTRIAN SIGNALS CROSSING MAIN STREET ON EASTSIDE OF CROSS STREET	H	H	H	H	H	H	H	H	H	H	H	H	H	H	H	H	H	H	*P	**FH	H	H	H	H	H	H	H	H	*P	**FH	H	H	H	
PEDESTRIAN SIGNALS CROSSING MAIN STREET ON WESTSIDE OF CROSS STREET	H	H	H	H	H	H	H	H	H	H	H	H	H	H	H	H	H	H	H	H	H	H	*P	**FH	H	H	H	H	*P	**FH	H	H	H	

* TO APPEAR ONLY UPON PUSHBUTTON ACTIVATION
** FLASHING IS TO TERMINATE AT THE COMPLETION OF THE PEDESTRIAN INTERVAL CLEARANCE.
THIS OR FLASHING INTERVAL MAY FINISH TIMING IN THE BIDIRECTIONAL STRAIGHT THROUGH MOVEMENT IF THE LEFT ARROW TIME IS NOT SUFFICIENT TO COMPLETE OR FLASHING INTERVALS.
 AND FLASHING TIMINGS TO BE SET ONLY ON PHASES WHERE AND FLASHING ARE INDICATED IN THE SEQUENCE OF OPERATION.
P = ILLUMINATED PERSON = WALK
FH = ILLUMINATED FLASHING HAND = FLASHING DON'T WALK
H = ILLUMINATED SOLID HAND = DON'T WALK

PHASE 2+6 SHALL BE PLACED ON RECALL.

NLT = "NO LEFT TURN" OR

NRT = "NO RIGHT TURN" OR

PROPOSED RAILROAD PREEMPTION SEQUENCE OF OPERATION

PROPOSED RAILROAD PREEMPTION SEQUENCE OF OPERATION														PREEMPTOR NUMBER 3		PREEMPTOR NUMBER 4		PREEMPTOR NUMBER 2						
CHANGE FROM NORMAL SEQUENCE OF OPERATION INTERVAL NUMBER	1	5			8			11			14		18		22		26							
CHANGE FROM EMERGENCY VEHICLE PREEMPTION SEQUENCE OF OPERATION INTERVAL NUMBER															2		3							
RAILROAD PREEMPTION SEQUENCE OF OPERATION INTERVAL NUMBER	1A	1B	1C	1D	1E	1F	1G	1H	1J	1K	1L	1M	1N	1P	1Q	1R	1S	2		3	4	5	CLEAR TO NORMAL SEQUENCE	
CHANGE TO RAILROAD PREEMPTION SEQUENCE OF OPERATION INTERVAL NUMBER	2	1C	2	1E	2	1G	2	2	1K	2	2	1N	2	1Q	2	1S	2	3		4	5			
MAIN STREET END MAST ARM AND FAR LEFT SIGNALS	R ←Y	Y	R	R	R	Y	R	R	R	R	R	R	R	Y	R	R	R	R		R	R	R	△	
MAIN STREET FAR RIGHT SIGNAL	R Y	Y	R	R	R	Y	R	R	R	R	R	R	R	Y	R	R	R	R		R	R	R	△	
MAIN STREET END MAST ARM AND FAR LEFT SIGNALS	R ←Y	R	R	Y	R	Y	R	R	R	R	R	R	R	Y	R	R	R	R		R	R	G ←G	△	
MAIN STREET FAR RIGHT SIGNAL	R Y	R	R	Y	R	Y	R	R	R	R	R	R	R	Y	R	R	R	R		R	R	G	△	
CROSS STREET END MAST ARM AND FAR LEFT SIGNALS	R Y	R	R	R	R	R	R	R ←G	R	R	G ←G	G	G	R	R	G	G	G ←G	Y	R	R	△		
CROSS STREET FAR RIGHT SIGNAL	R Y	R	R	R	R	R	R	R	R	R	G	G	G	R	R	G	G	G		Y	R	R	△	
CROSS STREET END MAST ARM AND FAR LEFT SIGNALS	R Y	R	R	R	R	R	R	R ←Y	Y	R	R	Y	R	R	R	Y	R	R		R	R	△		
CROSS STREET FAR RIGHT SIGNAL	R Y	R	R	R	R	R	R	R	Y	R	R	Y	R	R	R	Y	R	R		R	R	△		
PEDESTRIAN SIGNALS CROSSING CROSS STREET ON NORTHSIDE OF MAIN STREET	H	FH	H	H	H	FH	H	H	H	H	H	H	H	H	H	H	H	H		H	H	H	△	
PEDESTRIAN SIGNALS CROSSING CROSS STREET ON SOUTHSIDE OF MAIN STREET	H	H	H	FH	H	FH	H	H	H	H	H	H	H	H	H	H	H	H		H	H	H	△	
PEDESTRIAN SIGNALS CROSSING MAIN STREET ON EASTSIDE OF CROSS STREET	H	H	H	H	H	H	H	H	FH	H	H	FH	H	H	H	H	H	H		H	H	H	△	
PEDESTRIAN SIGNALS CROSSING MAIN STREET ON WESTSIDE OF CROSS STREET	H	H	H	H	H	H	H	H	H	H	FH	FH	H	H	H	H	H	H		H	H	H	△	
INTERNALLY ILLUMINATED NRT SIGNS	NRT	NRT	NRT	NRT	NRT	NRT	NRT	NRT	NRT	NRT	NRT	NRT	NRT	NRT	NRT	NRT	NRT	NRT		NRT	NRT	NRT	△	
INTERNALLY ILLUMINATED NLT SIGNS	NLT	NLT	NLT	NLT	NLT	NLT	NLT	NLT	NLT	NLT	NLT	NLT	NLT	NLT	NLT	NLT	NLT	NLT		NLT	NLT	NLT	△	
																						HOLD		

△ RAILROAD PREEMPTION SEQUENCE SHALL PROVIDE THE PROPER CLEARANCE INTERVAL TO RESUME THE NORMAL SEQUENCE OF OPERATION OR PROPER CLEARANCE INTERVAL TO DISPLAY AN EMERGENCY VEHICLE INTERVAL (IF APPLICABLE) AFTER RAILROAD PREEMPTION INTERVAL 5 IS TERMINATED.

HOLD

MODEL Default
FILE Name: P:\projects\1901\0001\CCADD\CAD Sheets\1901-14-elt-5-rd-bis.dgn



USER NAME = mohammed.ait	DESIGNED - RH	REVISED -
	DRAWN - CW	REVISED -
PLOT SCALE = 100,0000 ' / in.	CHECKED - TDM	REVISED -
PLOT DATE = 9/2/2025	DATE - 01/11/2025	REVISED -

STATE OF ILLINOIS
DEPARTMENT OF TRANSPORTATION


WOODFIELD ROAD
HIGHWAY STANDARDS -
EMERGENCY VEHICLE PREEMPTION - SEQUENCE OF OPERATION

SCALE: N/A SHEET 16 OF 16 SHEETS STA. N/A TO STA. N/A

F.A.U RTE.	SECTION	COUNTY	TOTAL SHEETS	SHEET NO.
3073	20-00134-00-RS	COOK	166	150
TS-08		CONTRACT NO. 61L43		
		ILLINOIS	FED. AID PROJECT	

FINAL SURVEY NO.	SURVEYED NOTE BOOK	PLOTTED TEMPLATE	DATE

ORIGINAL SURVEY NO.	SURVEYED NOTE BOOK	PLOTTED TEMPLATE	DATE

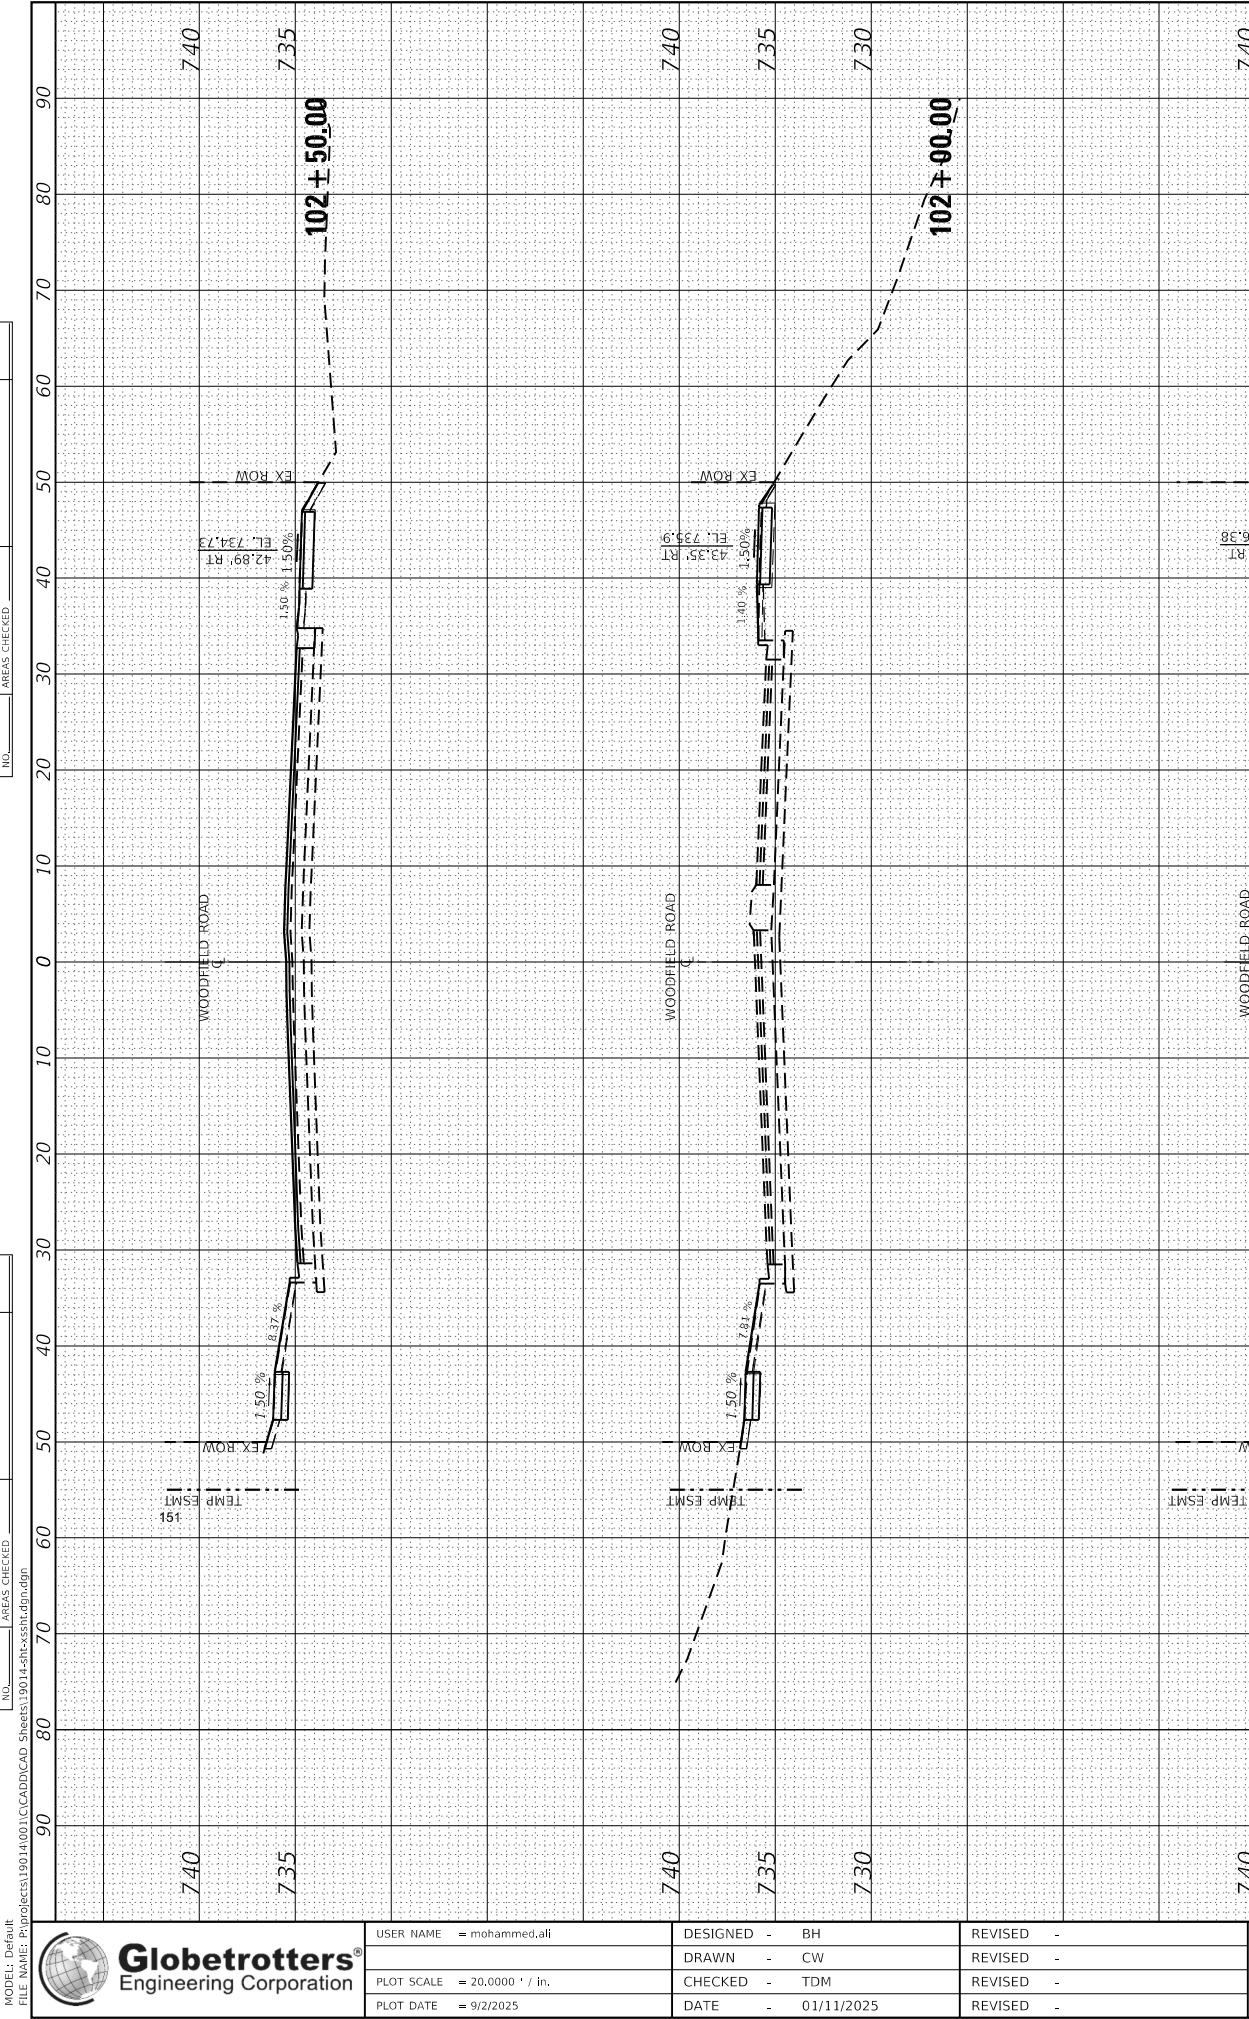

USER NAME = mohammed.ali	DESIGNED - BH
PLOT SCALE = 20,0000 ' / in.	DRAWN - CW
PLOT DATE = 9/2/2025	CHECKED - TDM
	DATE - 01/11/2025

REVISED -
REVISED -
REVISED -
REVISED -

STATE OF ILLINOIS
DEPARTMENT OF TRANSPORTATION


WOODFIELD ROAD
CROSS SECTIONS

SCALE: H: 1" = 10' V: 1" = 5' SHEET 1 OF 14 STA. 100+00.00 TO STA. 102+50.00

F.A.U RTE.	SECTION	COUNTY	TOTAL SHEETS	SHEET NO.
3073	20-00134-00-RS	COOK	166	151
CONTRACT NO. 61L43				
ILLINOIS FED. AID PROJECT				

FINAL SURVEY	SURVEYED	BY	DATE
NO.	NOTE BOOK		
	AREAS		
	CHECKED		

ORIGINAL SURVEY	SURVEYED	BY	DATE
NO.	NOTE BOOK		
	AREAS		
	CHECKED		

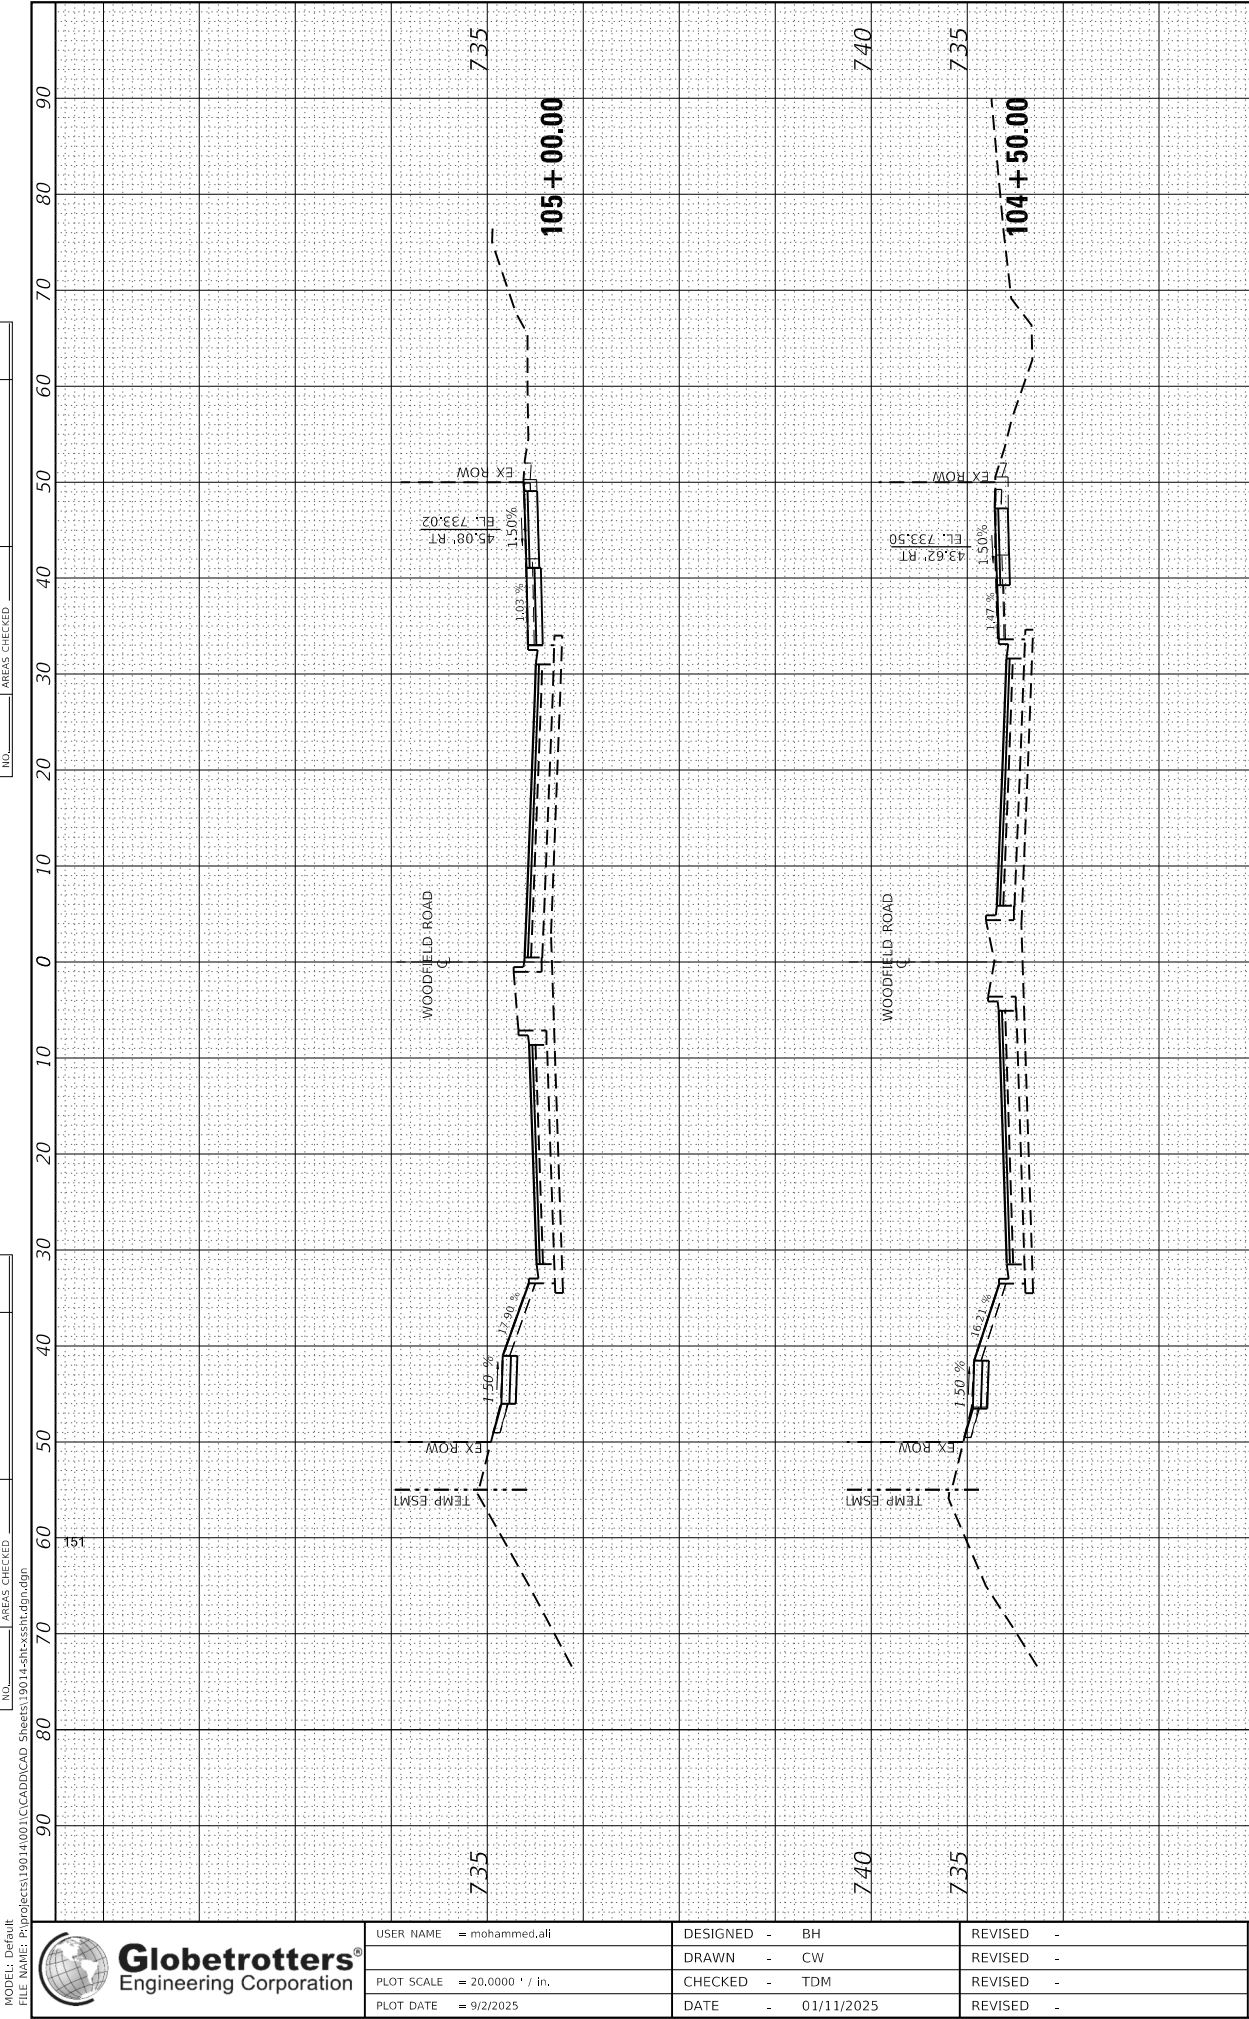

STATE OF ILLINOIS
DEPARTMENT OF TRANSPORTATION

WOODFIELD ROAD
CROSS SECTIONS

SCALE: H: 1" = 10'
V: 1" = 5'

SHEET 2 OF 14

STA. 102+79.23 TO STA. 105+00.00


F.A.U RTE.	SECTION	COUNTY	TOTAL SHEETS	SHEET NO.
3073	20-00134-00-R5	COOK	166	152
CONTRACT NO. 61L43				
ILLINOIS FED. AID PROJECT				

FINAL SURVEY	SURVEYED NOTE BOOK	BY	DATE
NO.	AREAS CHECKED		

ORIGINAL SURVEY	SURVEYED NOTE BOOK	BY	DATE
NO.	AREAS CHECKED		

MODEL Default

FILE NAME: P:\projects\1901\001\CAD\CADD\CAD Sheets\1901420t-xss01.dgn

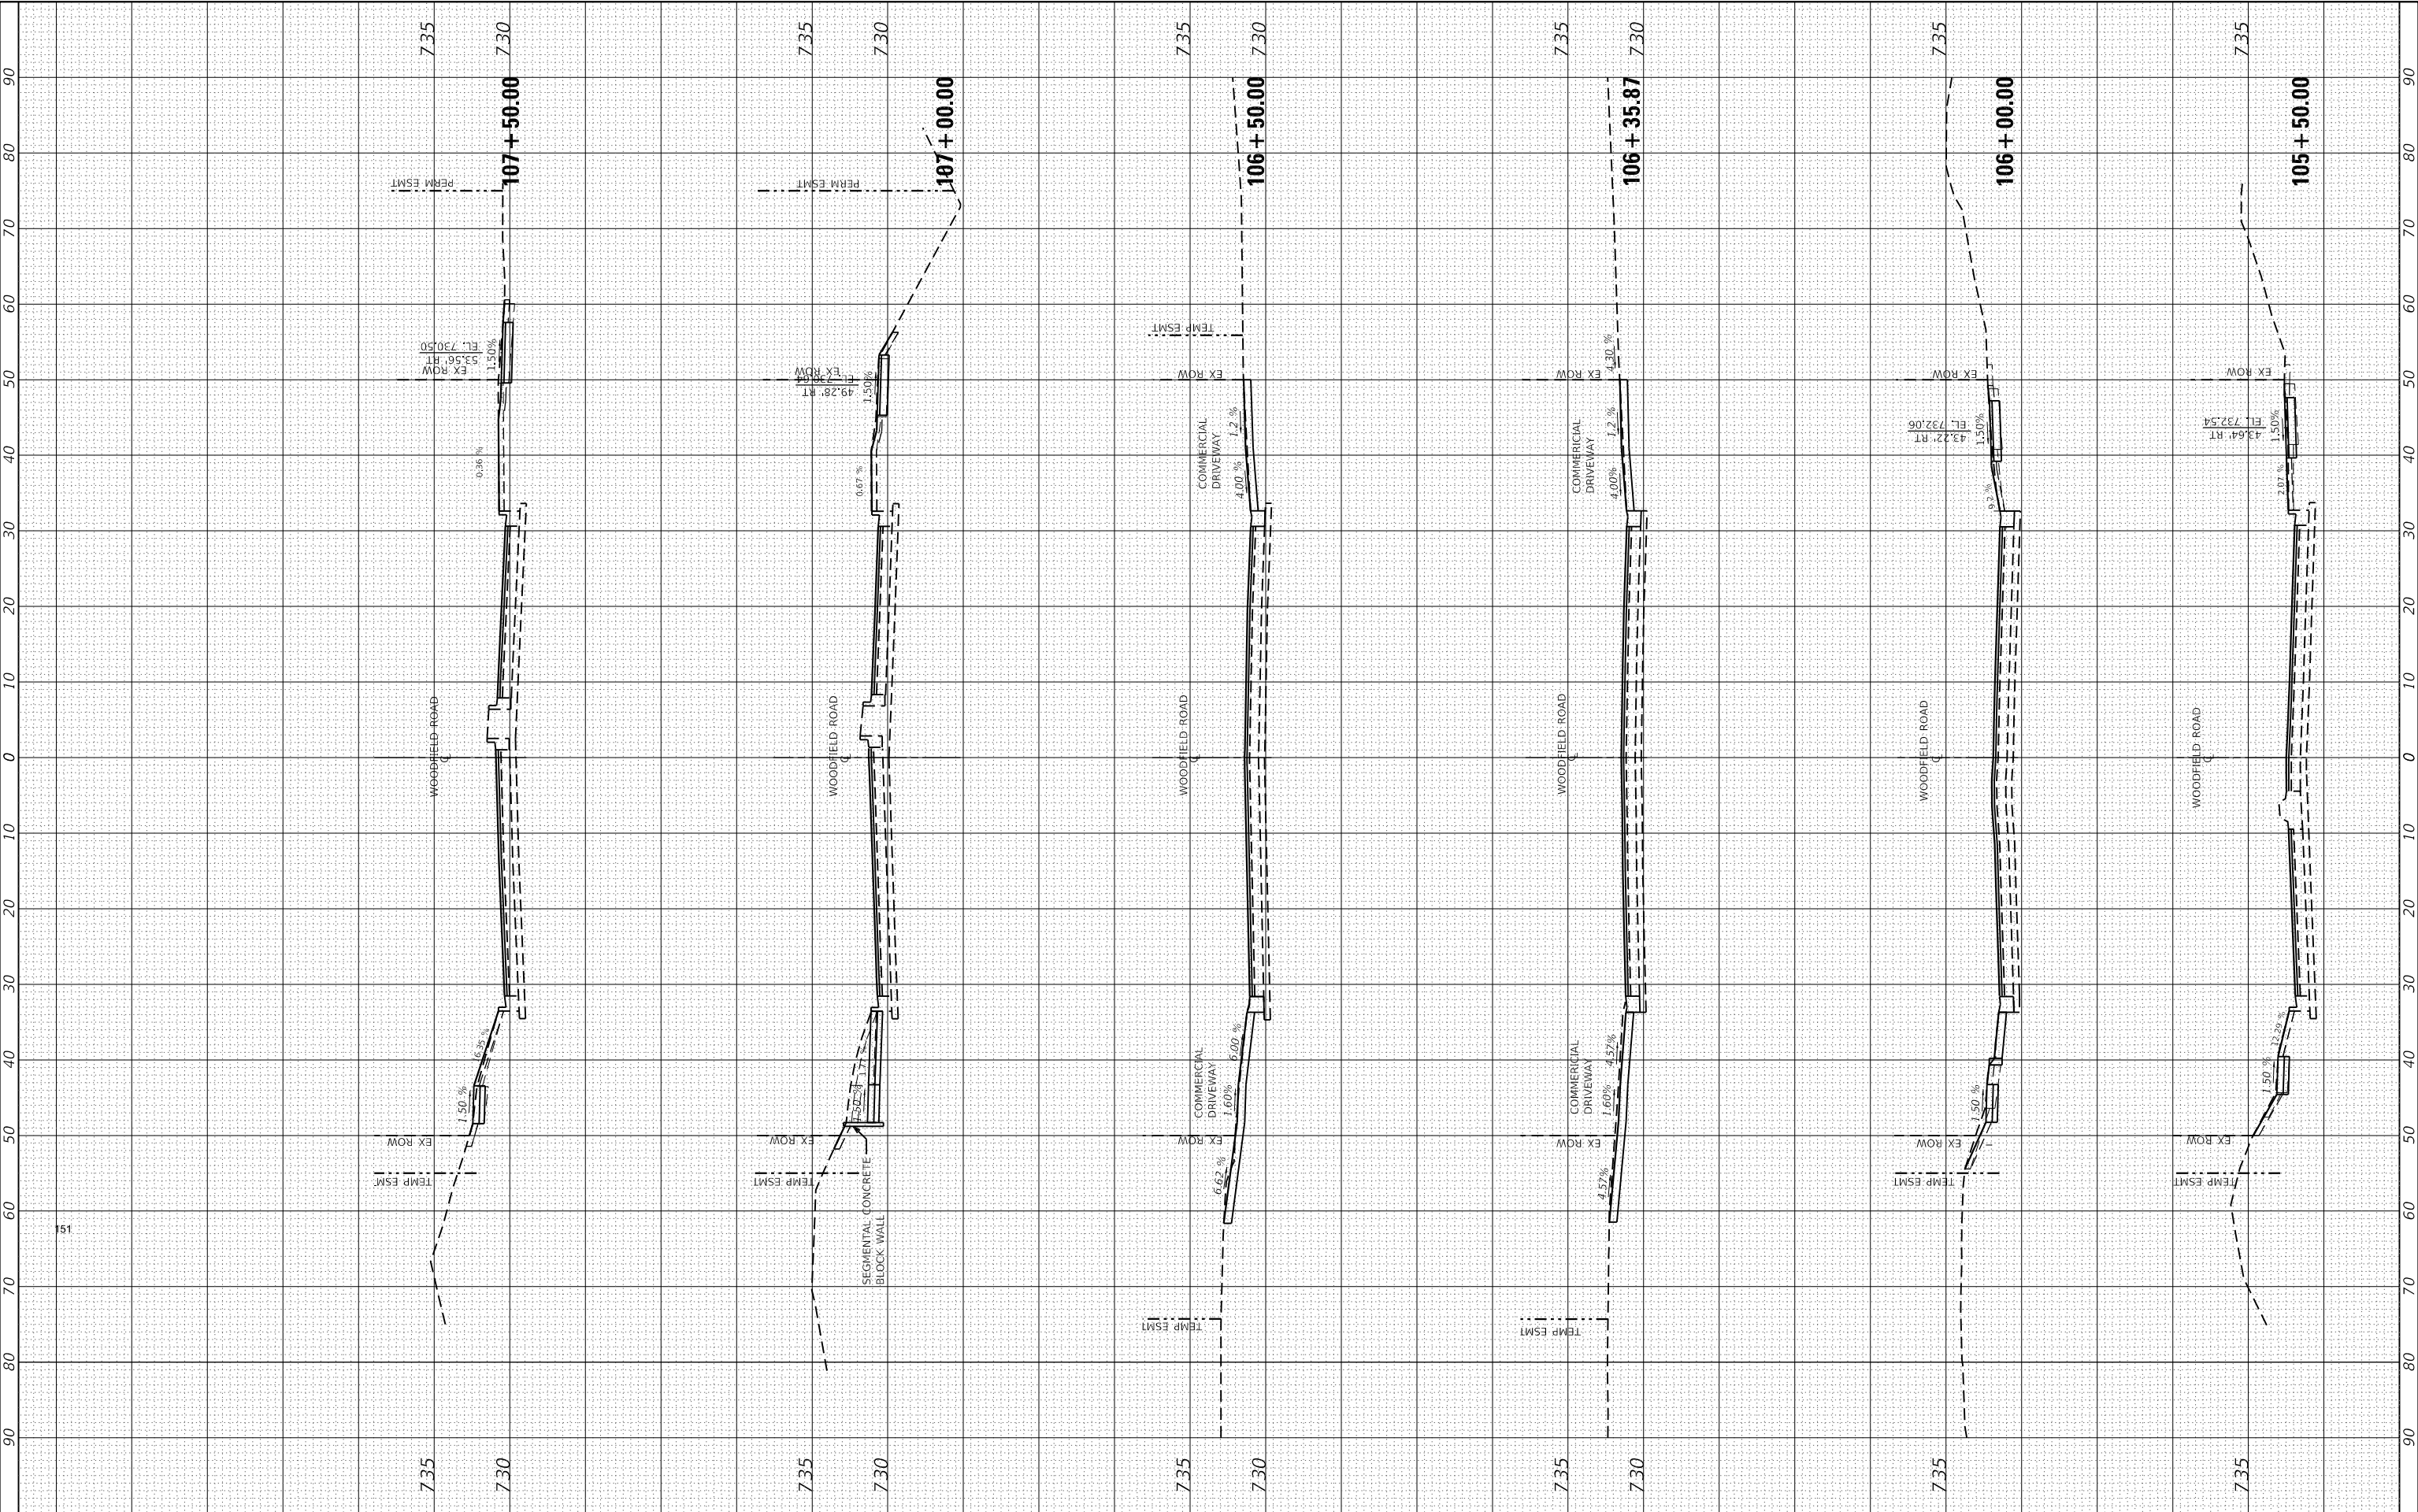


	USER NAME = mohammed.ali	DESIGNED - BH	REVISED -	STATE OF ILLINOIS DEPARTMENT OF TRANSPORTATION	WOODFIELD ROAD CROSS SECTIONS				F.A.U RTE.	SECTION	COUNTY	TOTAL SHEETS	SHEET NO.
		DRAWN - CW	REVISED -						3073	20-00134-00-R5	COOK	166	153
	PLOT SCALE = 20.0000 ' / in.	CHECKED - TDM	REVISED -						CONTRACT NO. 61143				
	PLOT DATE = 9/2/2025	DATE 01/11/2025	REVISED -						ILLINOIS FED. AID PROJECT				

SCALE: 1" = 10' 1/2" = 10' SHEET 3 OF 14 STA. 105+50.00 TO STA. 107+50.00

FINAL SURVEY NO.	SURVEYED PLOTTED NOTE BOOK AREAS CHECKED	BY	DATE

ORIGINAL SURVEY NO.	SURVEYED PLOTTED NOTE BOOK AREAS CHECKED	BY	DATE

MODEL Default
FILE NAME: P:\projects\19014\001\CADD\CAD Sheets\19014-201-CrossSection.dgn

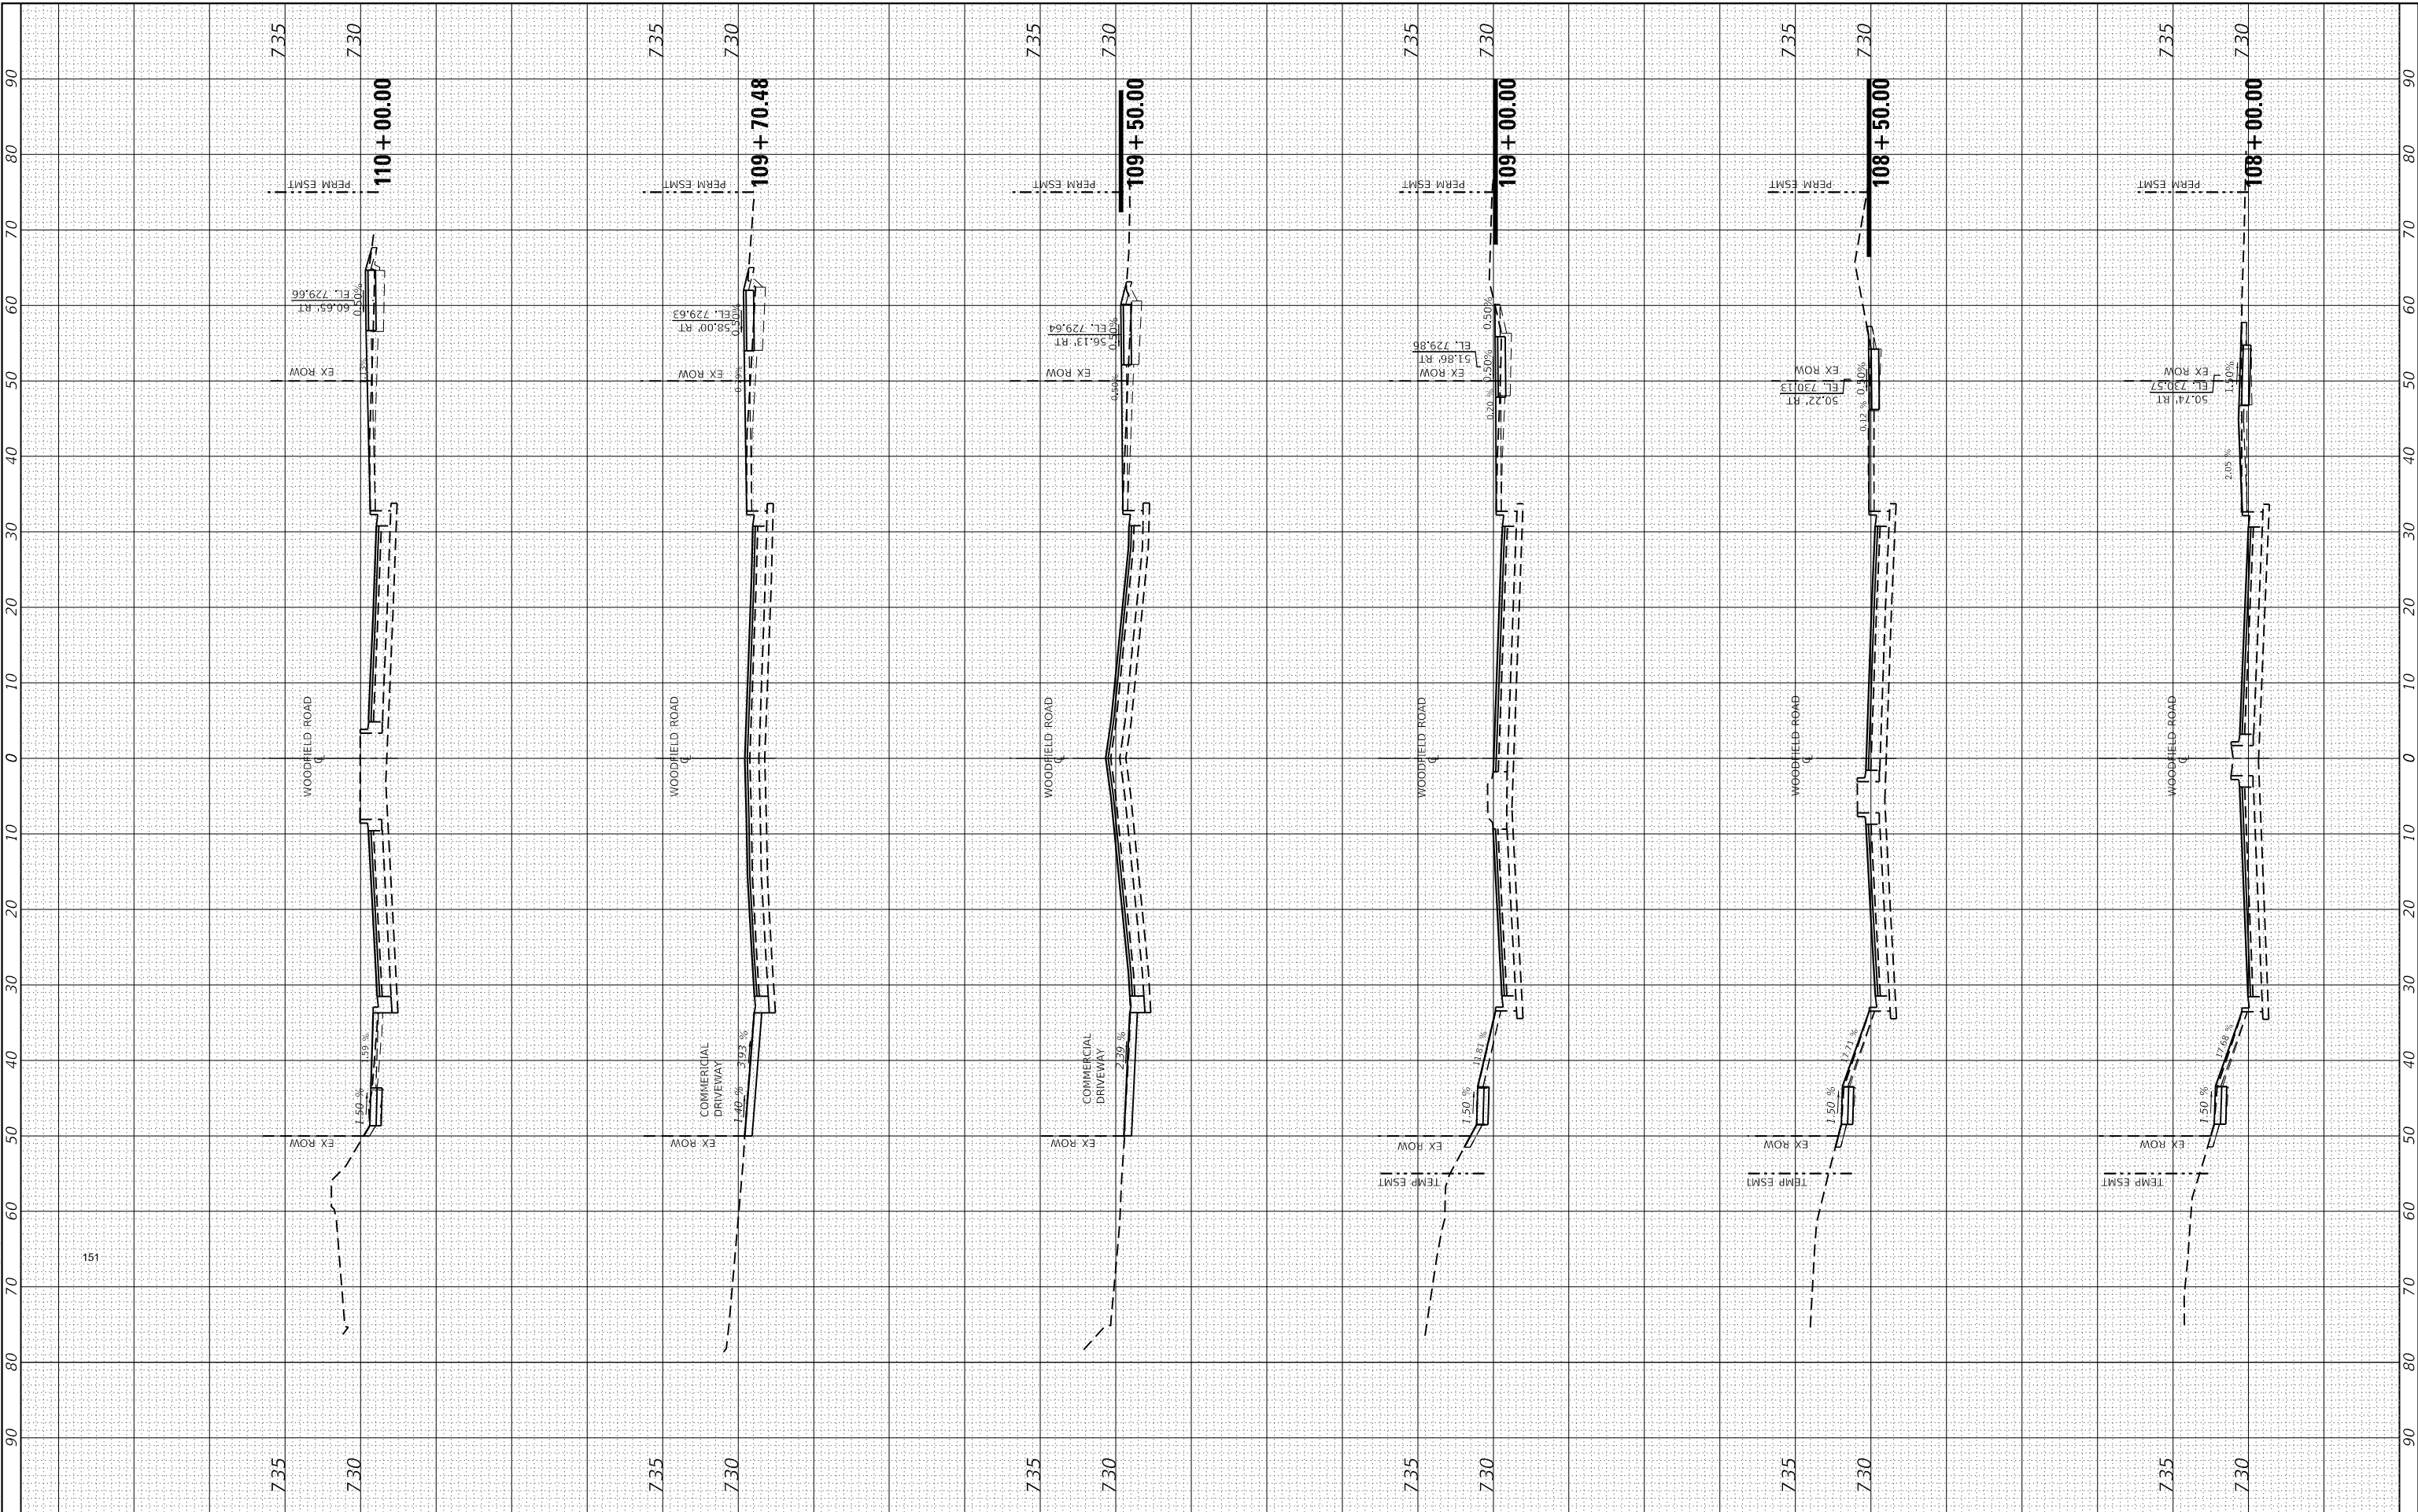



USER NAME = mohammed.ali	DESIGNED - BH	REVISED -
	DRAWN - CW	REVISED -
PLOT SCALE = 20,0000 ' / in.	CHECKED - TDM	REVISED -
PLOT DATE = 9/2/2025	DATE - 01/11/2025	REVISED -

STATE OF ILLINOIS
DEPARTMENT OF TRANSPORTATION


SCALE: $\frac{1"}{20'}$ = $\frac{100'}{20'}$
SHEET 4 OF 14

WOODFIELD ROAD
CROSS SECTIONS
STA. 108+00.00 TO STA. 110+00.00

F.A.U RTE.	SECTION	COUNTY	TOTAL SHEETS	SHEET NO.
3073	20-00134-00-R5	COOK	166	154
CONTRACT NO. 61L43				
ILLINOIS		FED. AID PROJECT		

FINAL SURVEY NO.	SURVEYED NOTE BOOK	PLOTTED TEMPLATE	BY	DATE

ORIGINAL SURVEY NO.	SURVEYED NOTE BOOK	PLOTTED TEMPLATE	BY	DATE

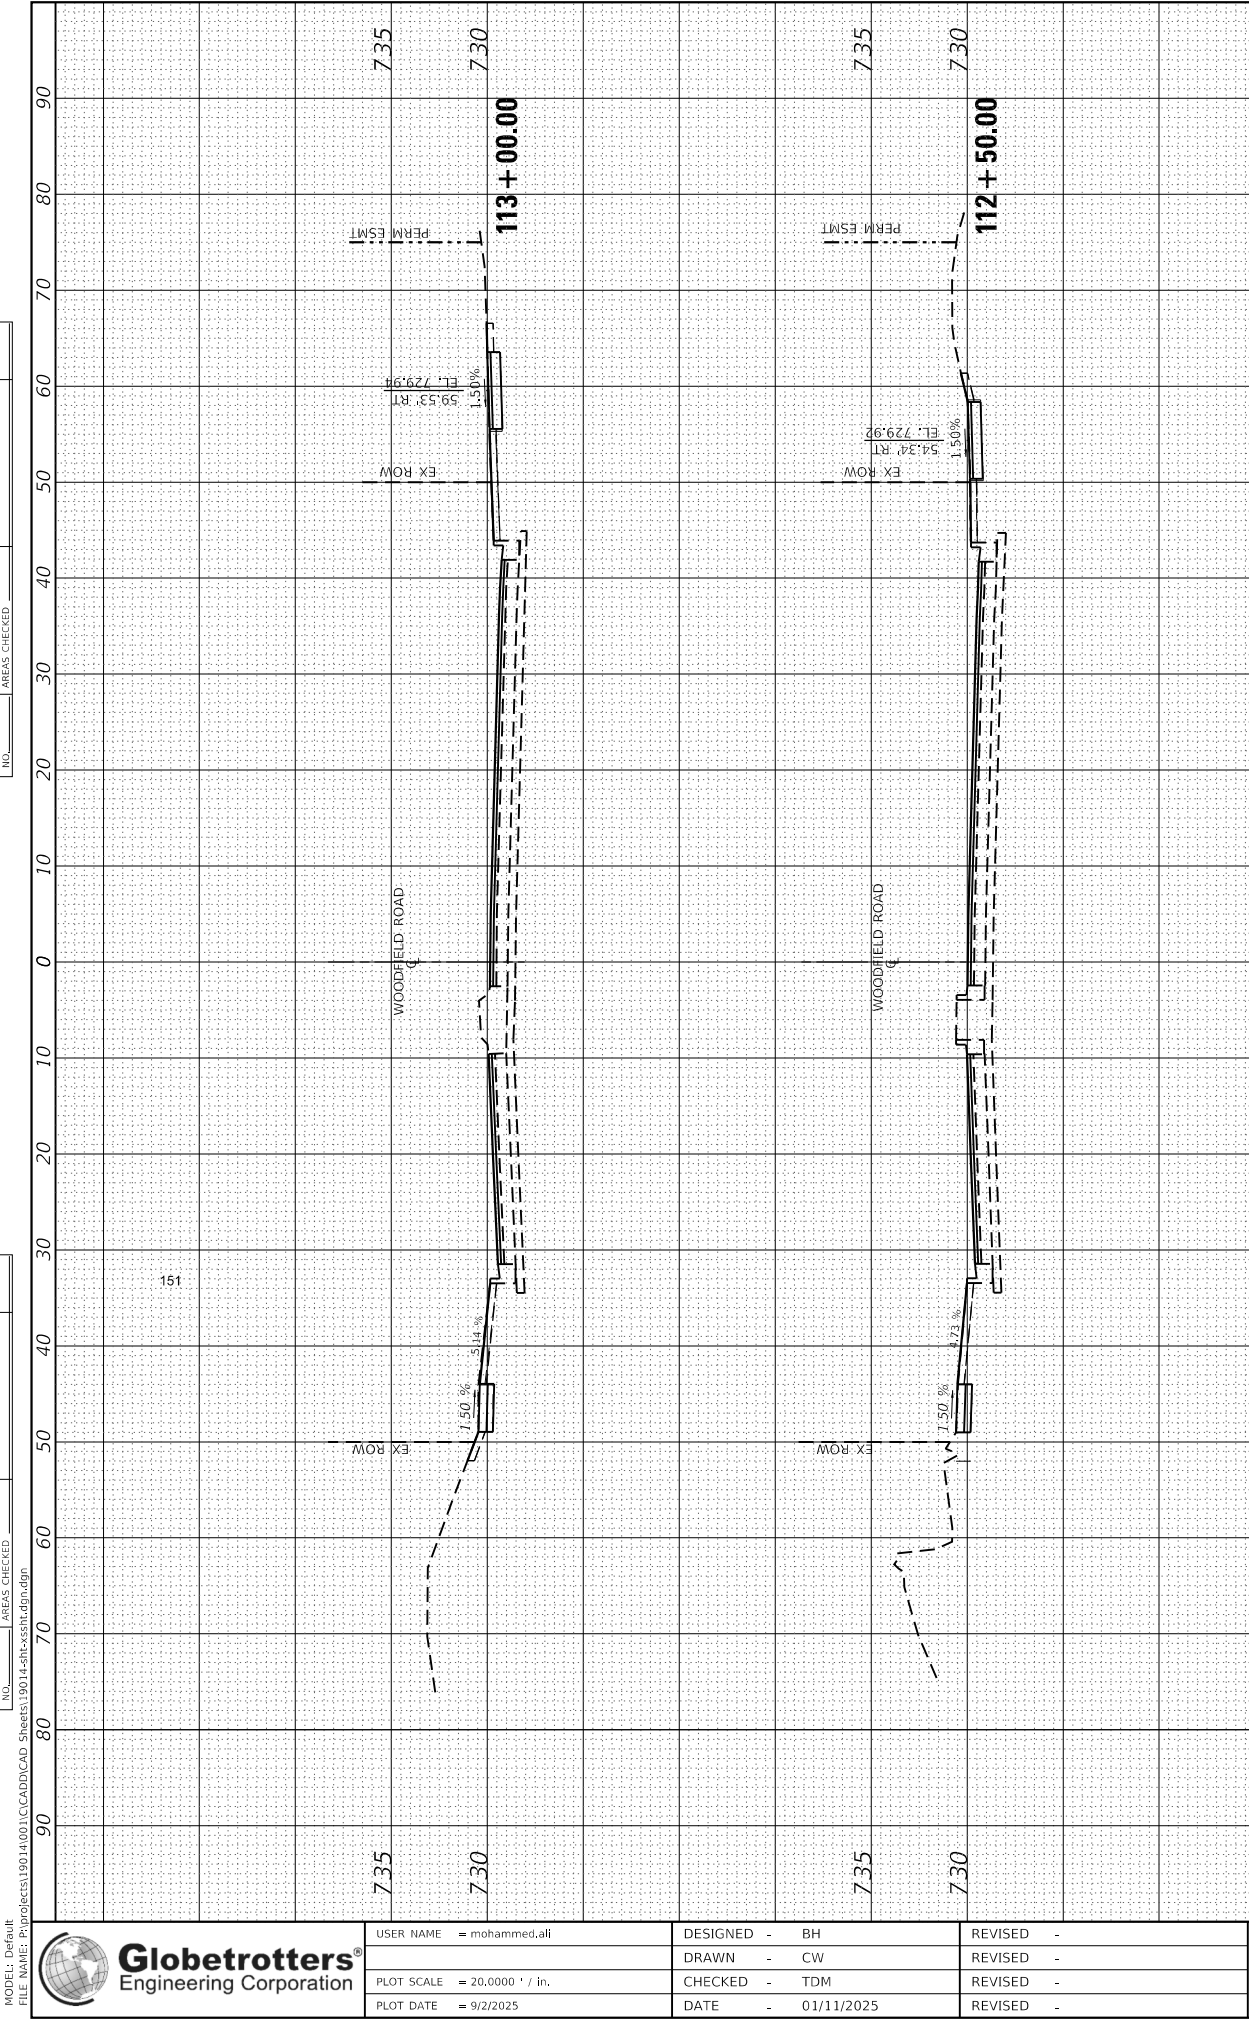

USER NAME	= mohammed.ali
DESIGNED	- BH
DRAWN	- CW
CHECKED	- TDM
DATE	- 01/11/2025
REVISD	-
REVISD	-
REVISD	-
REVISD	-

STATE OF ILLINOIS
DEPARTMENT OF TRANSPORTATION

WOODFIELD ROAD
CROSS SECTIONS

SCALE: $\frac{1}{2}$ " = 10'	SHEET 5 OF 14	STA. 110+50.00 TO STA. 113+00.00
------------------------------	---------------	----------------------------------

F.A.U RTE.	SECTION	COUNTY	TOTAL SHEETS	SHEET NO.
3073	20-00134-00-R5	COOK	166	155
CONTRACT NO. 61L43				
ILLINOIS FED. AID PROJECT				

ORIGINAL SURVEY	SURVEYED _____	BY _____	DATE _____
	PLOTTED _____		
	TEMPLATE _____		
	AREAS _____		
NO. _____	AREAS CHECKED _____		



Globetrotters[®]
Engineering Corporation

DESIGNED -	BH	REVISED -
DRAWN -	CW	REVISED -
CHECKED -	TDM	REVISED -
DATE -	01/11/2025	REVISED -


WOODFIELD ROAD CROSS SECTIONS

F.A.U RTE.	SECTION	COUNTY	TOTAL SHEETS	SHEET NO.
3073	20-00134-00-R5	COOK	166	156
		CONTRACT NO. 61L43		
ILLINOIS		FED. AID PROJECT		

FINAL SURVEY	SURVEYED PLOTTED	BY	DATE
NO. _____	AREAS CHECKED		
NOTE BOOK	TEMPLATE		
	AREAS		
	CHECKED		

ORIGINAL SURVEY	SURVEYED PLOTTED	BY	DATE
NO. _____	AREAS CHECKED		
NOTE BOOK	TEMPLATE		
	AREAS		
	CHECKED		

MODEL Default
FILE NAME: P:\projects\19014\001\CADD\CAD Sheets\19014-001-SS01.dgn

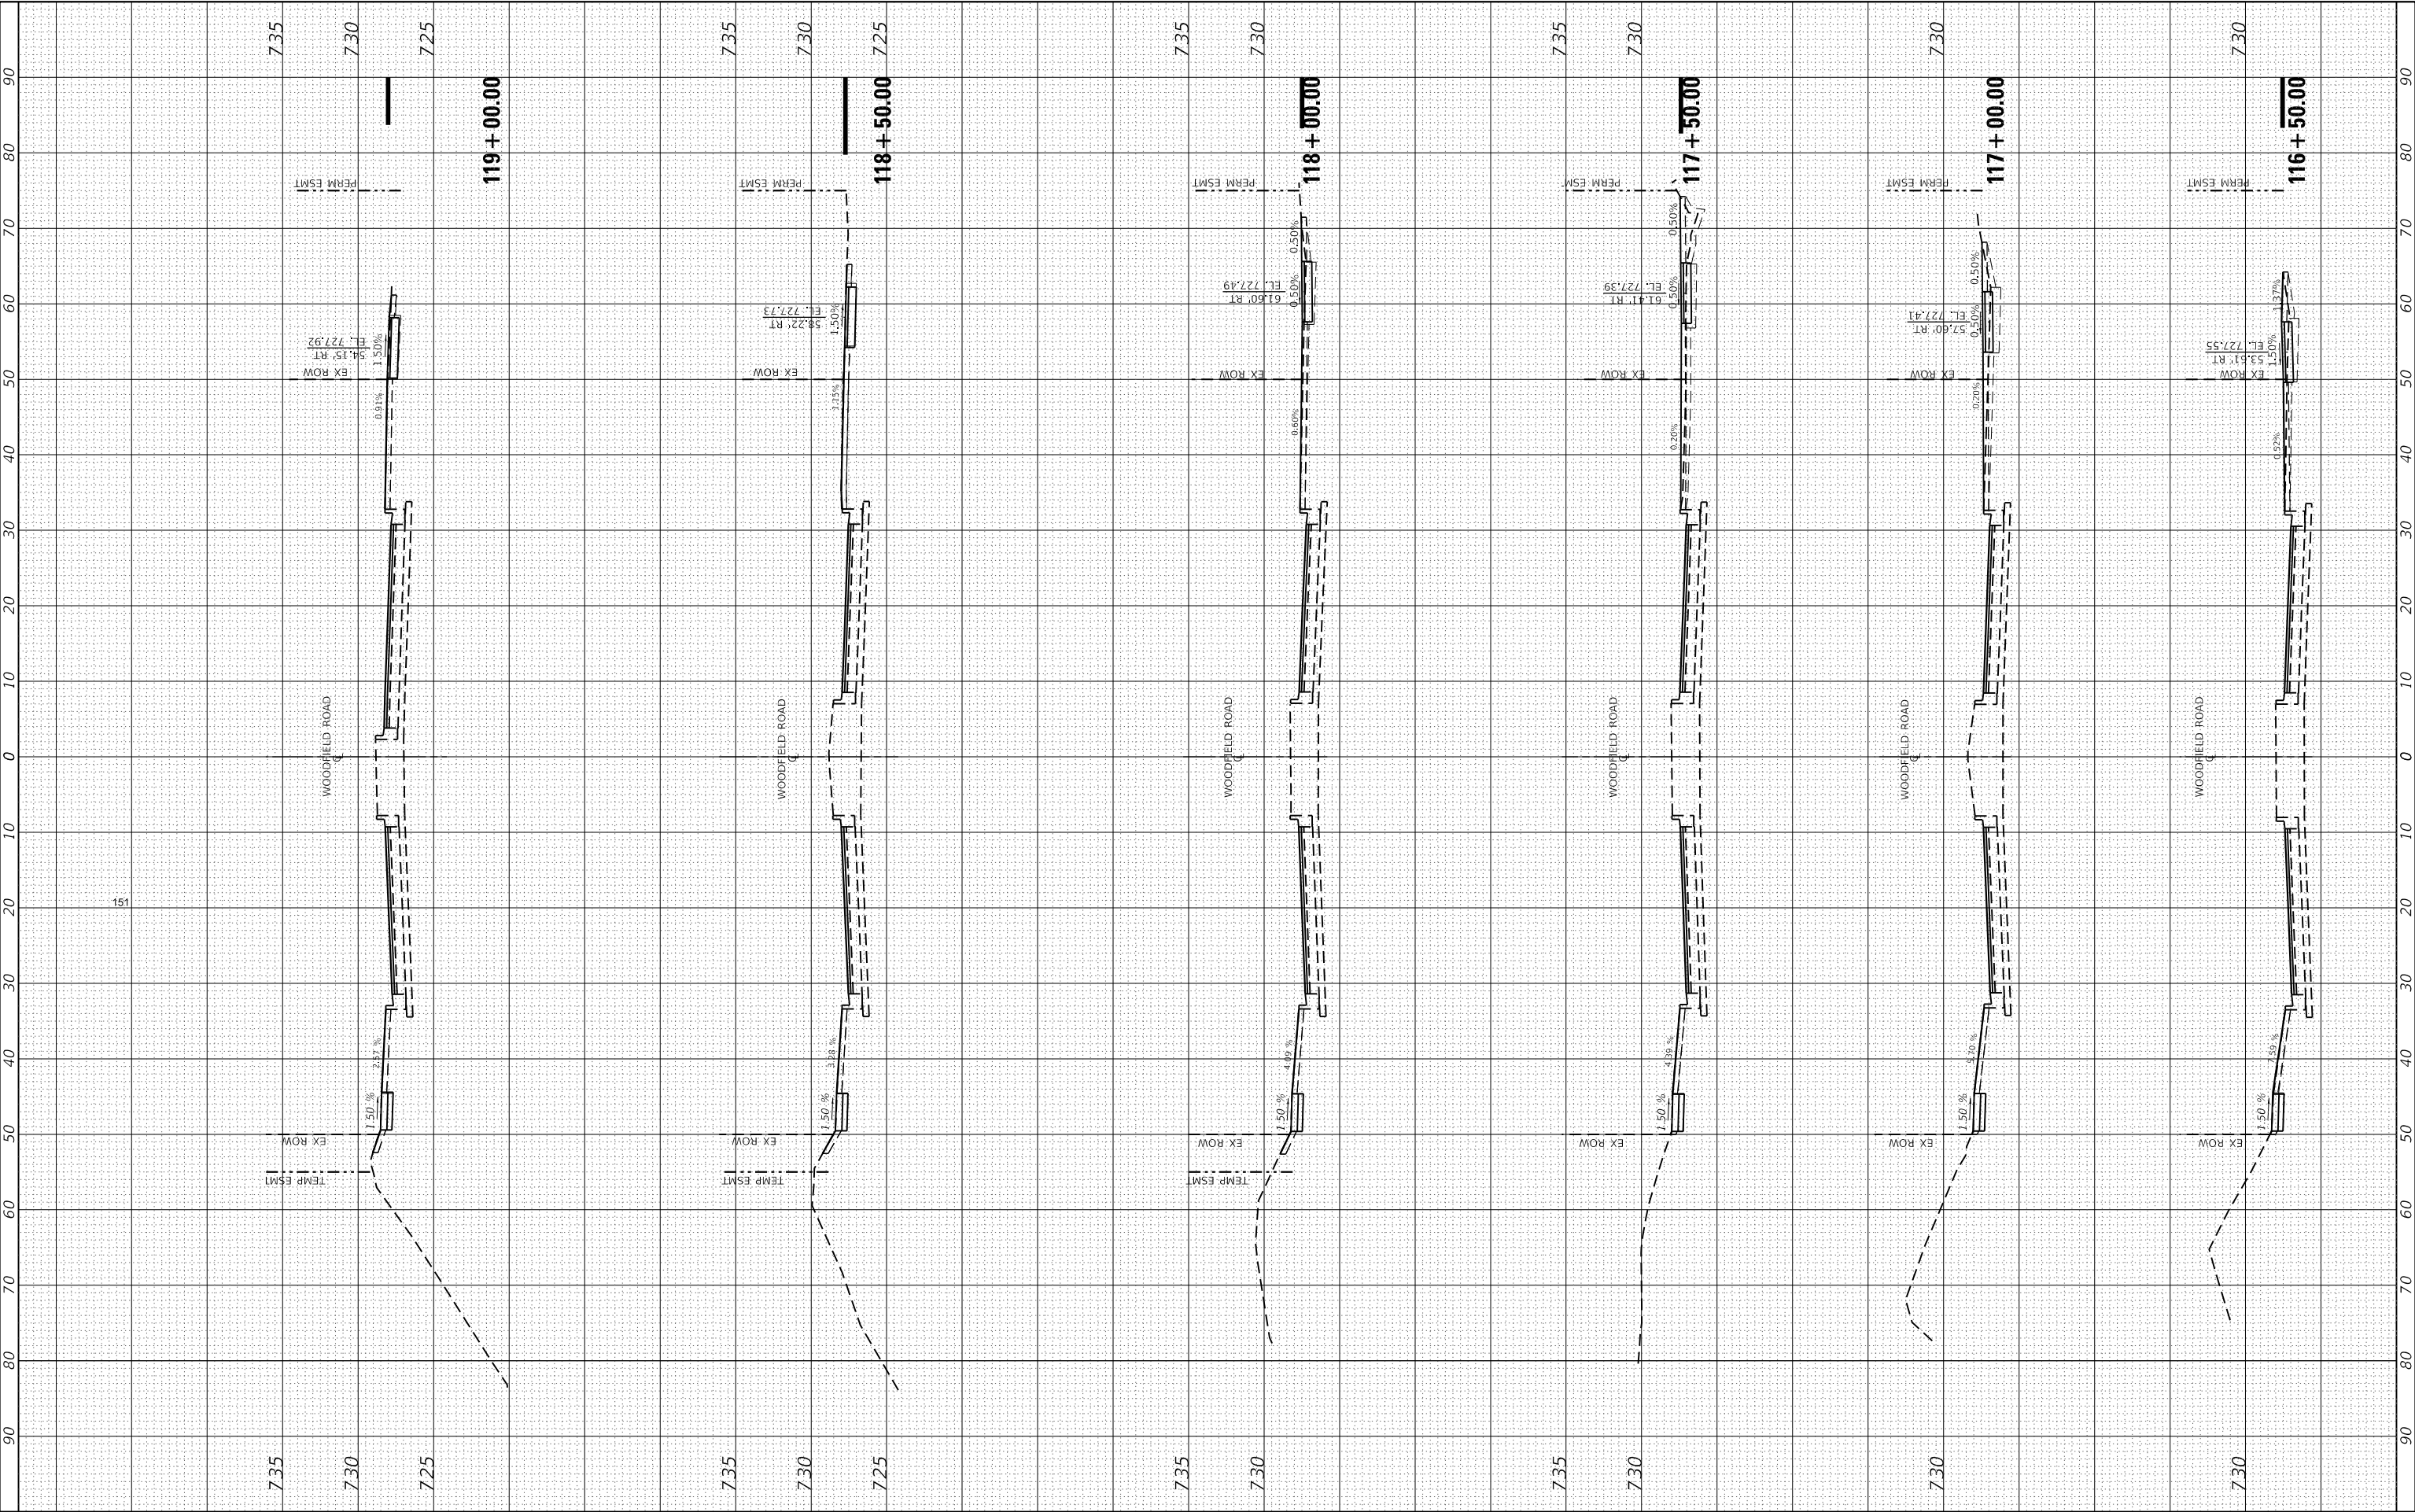

	USER NAME = mohammed.ali	DESIGNED - BH	REVISED -	STATE OF ILLINOIS DEPARTMENT OF TRANSPORTATION	SCALE: $\frac{1"}{40'}$ = $\frac{100'}{40'}$	SHEET 7 OF 14	WOODFIELD ROAD CROSS SECTIONS	TO STA. 119+00.00	F.A.U RTE. 3073	SECTION 20-00134-00-R5	COUNTY COOK	TOTAL SHEETS 166	SHEET NO. 157
	PLOT SCALE = 20,0000 ' / in.	CHECKED - TDM	REVISED -										
	PLOT DATE = 9/2/2025	DATE - 01/11/2025	REVISED -										

ILLINOIS	FED. AID PROJECT
----------	------------------

ORIGINAL SURVEY	SURVEYED _____	BY _____	DATE _____
	PLOTTED _____		
	TEMPLATE _____		
	AREAS _____		
NO. _____	AREAS CHECKED _____		




Globetrotters[®]
Engineering Corporation

DESIGNED - BH	REVISED -
DRAWN - CW	REVISED -
CHECKED - TDM	REVISED -
DATE 01/11/2025	REVISED


WOODFIELD ROAD CROSS SECTIONS

SCALE: H: 1" = 10' V: 1" = 5'	SHEET 8 OF 14	STA. 119+50.00 TO STA. 121+00.00
----------------------------------	---------------	----------------------------------

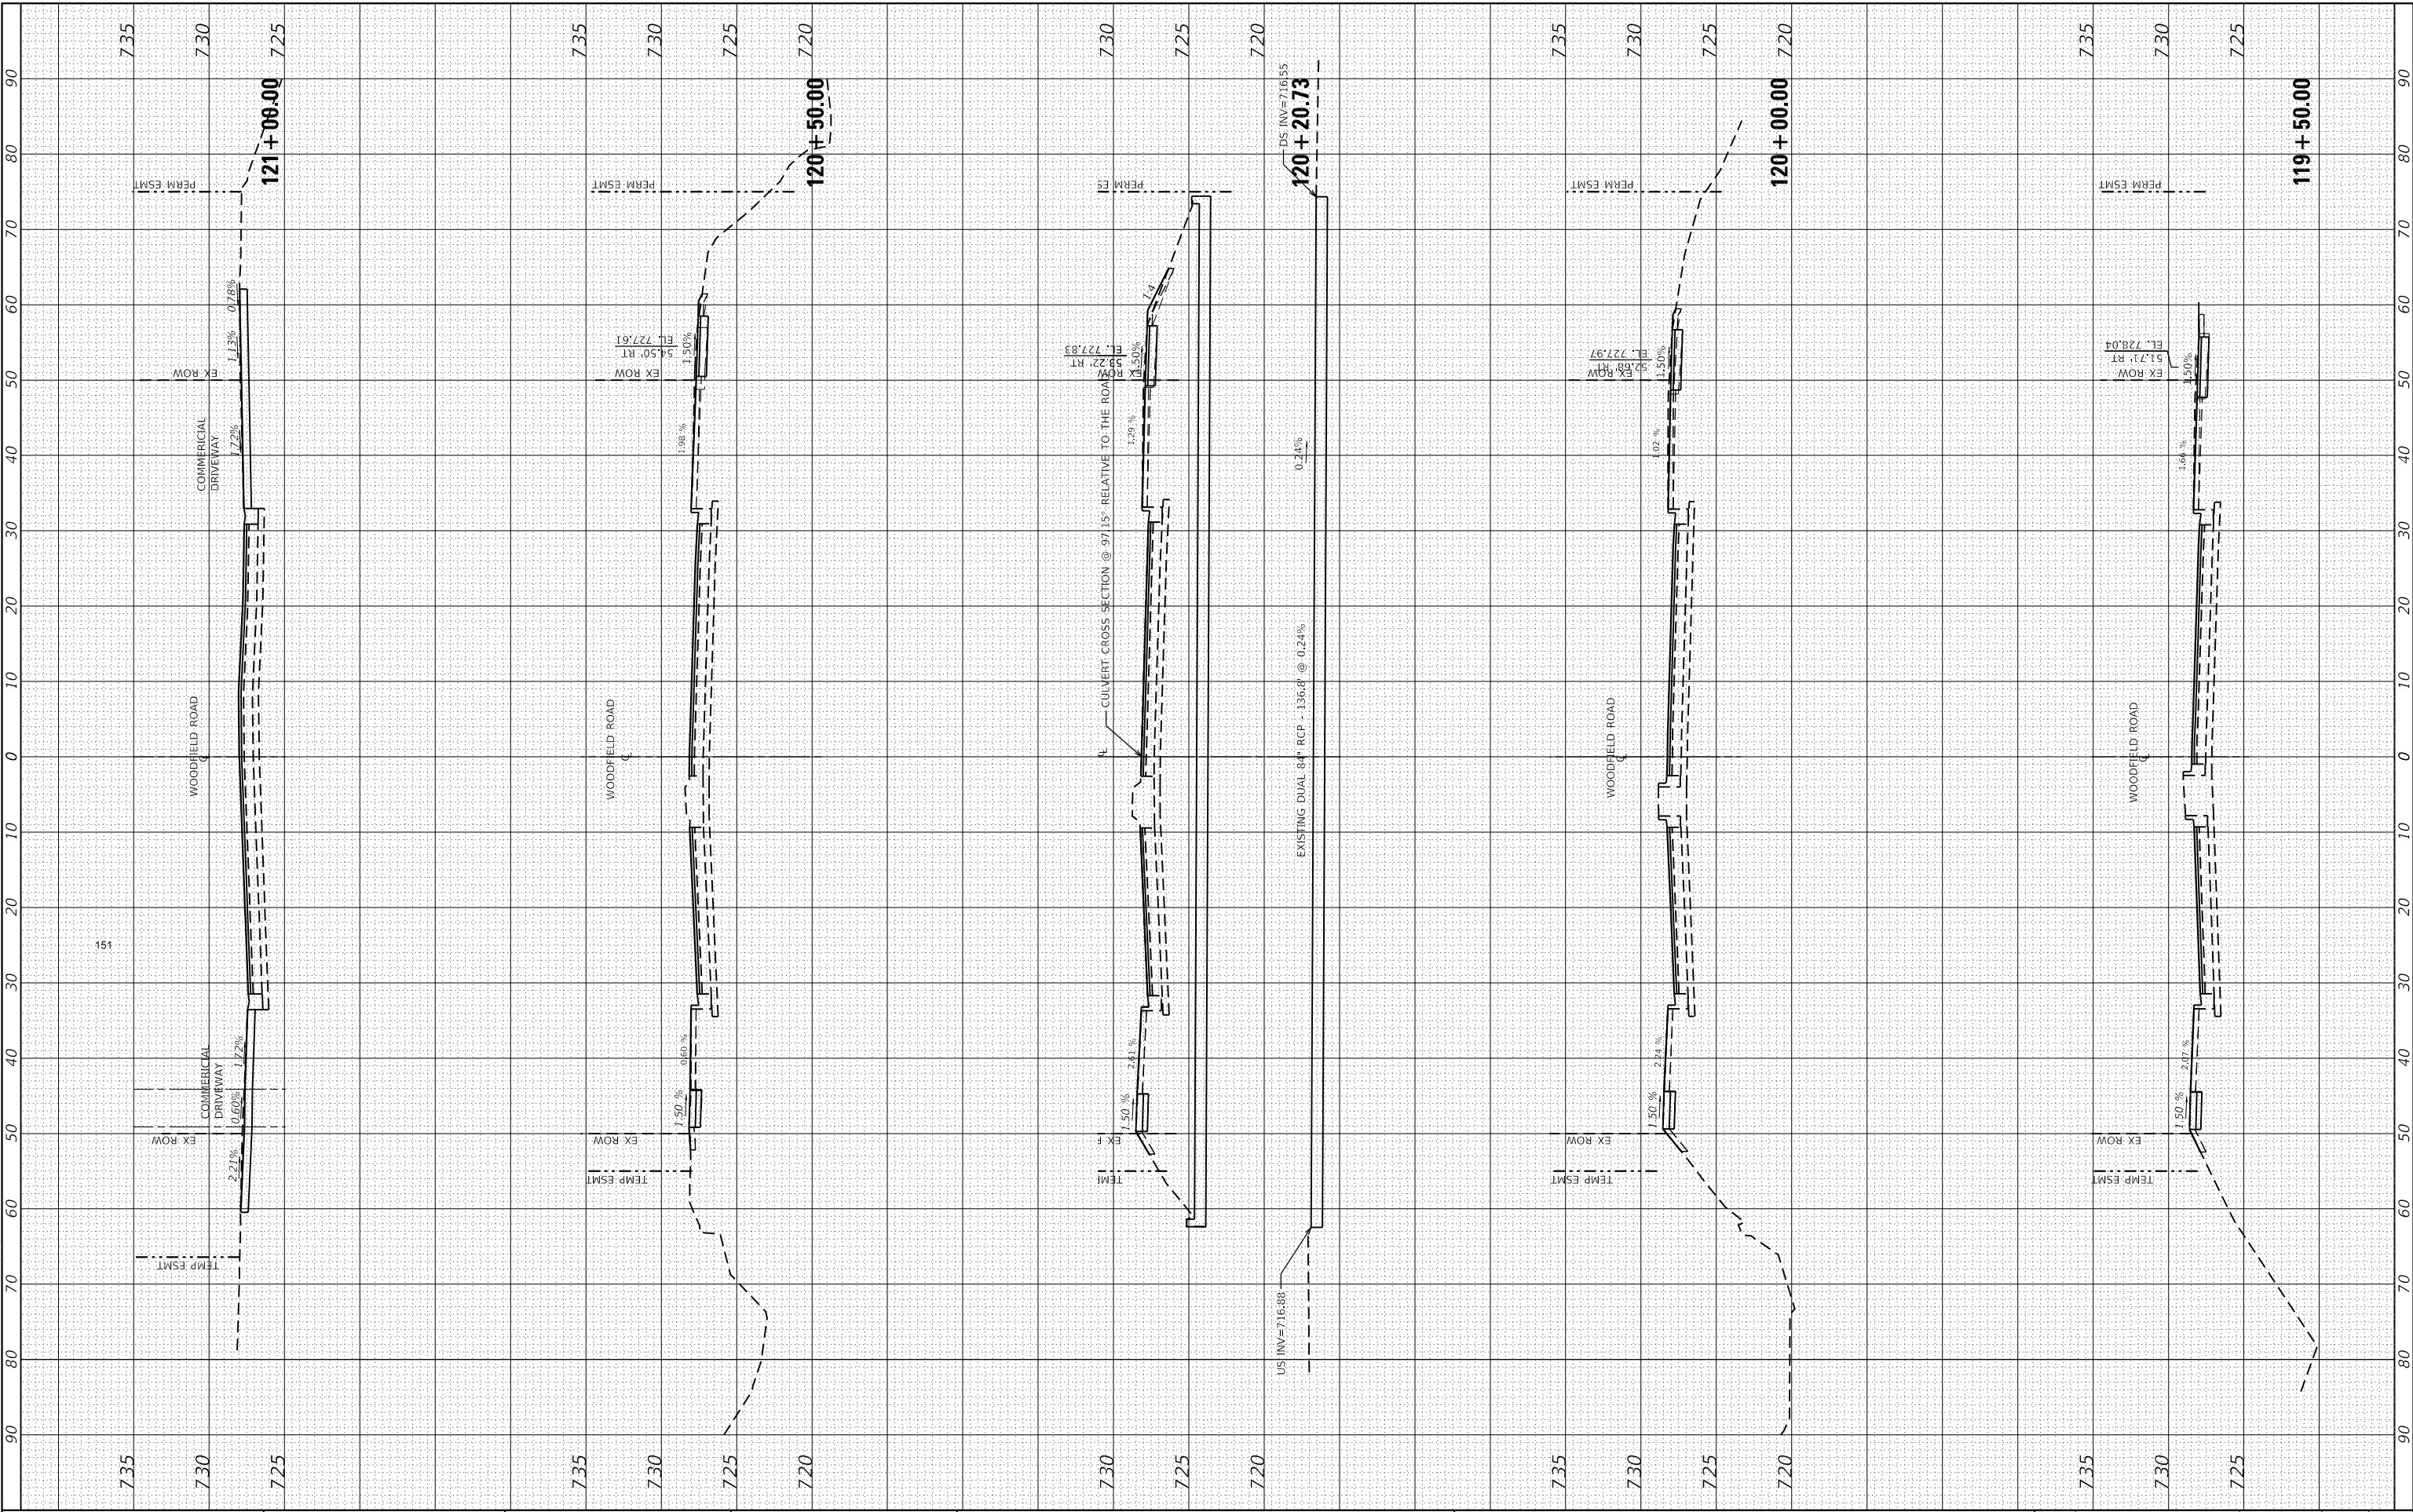

FINAL SURVEY NOTE BOOK NO.	SURVEYED PLOTTED TEMPLATE AREAS CHECKED	BY	DATE

ORIGINAL SURVEY NOTE BOOK NO.	SURVEYED PLOTTED TEMPLATE AREAS CHECKED	BY	DATE

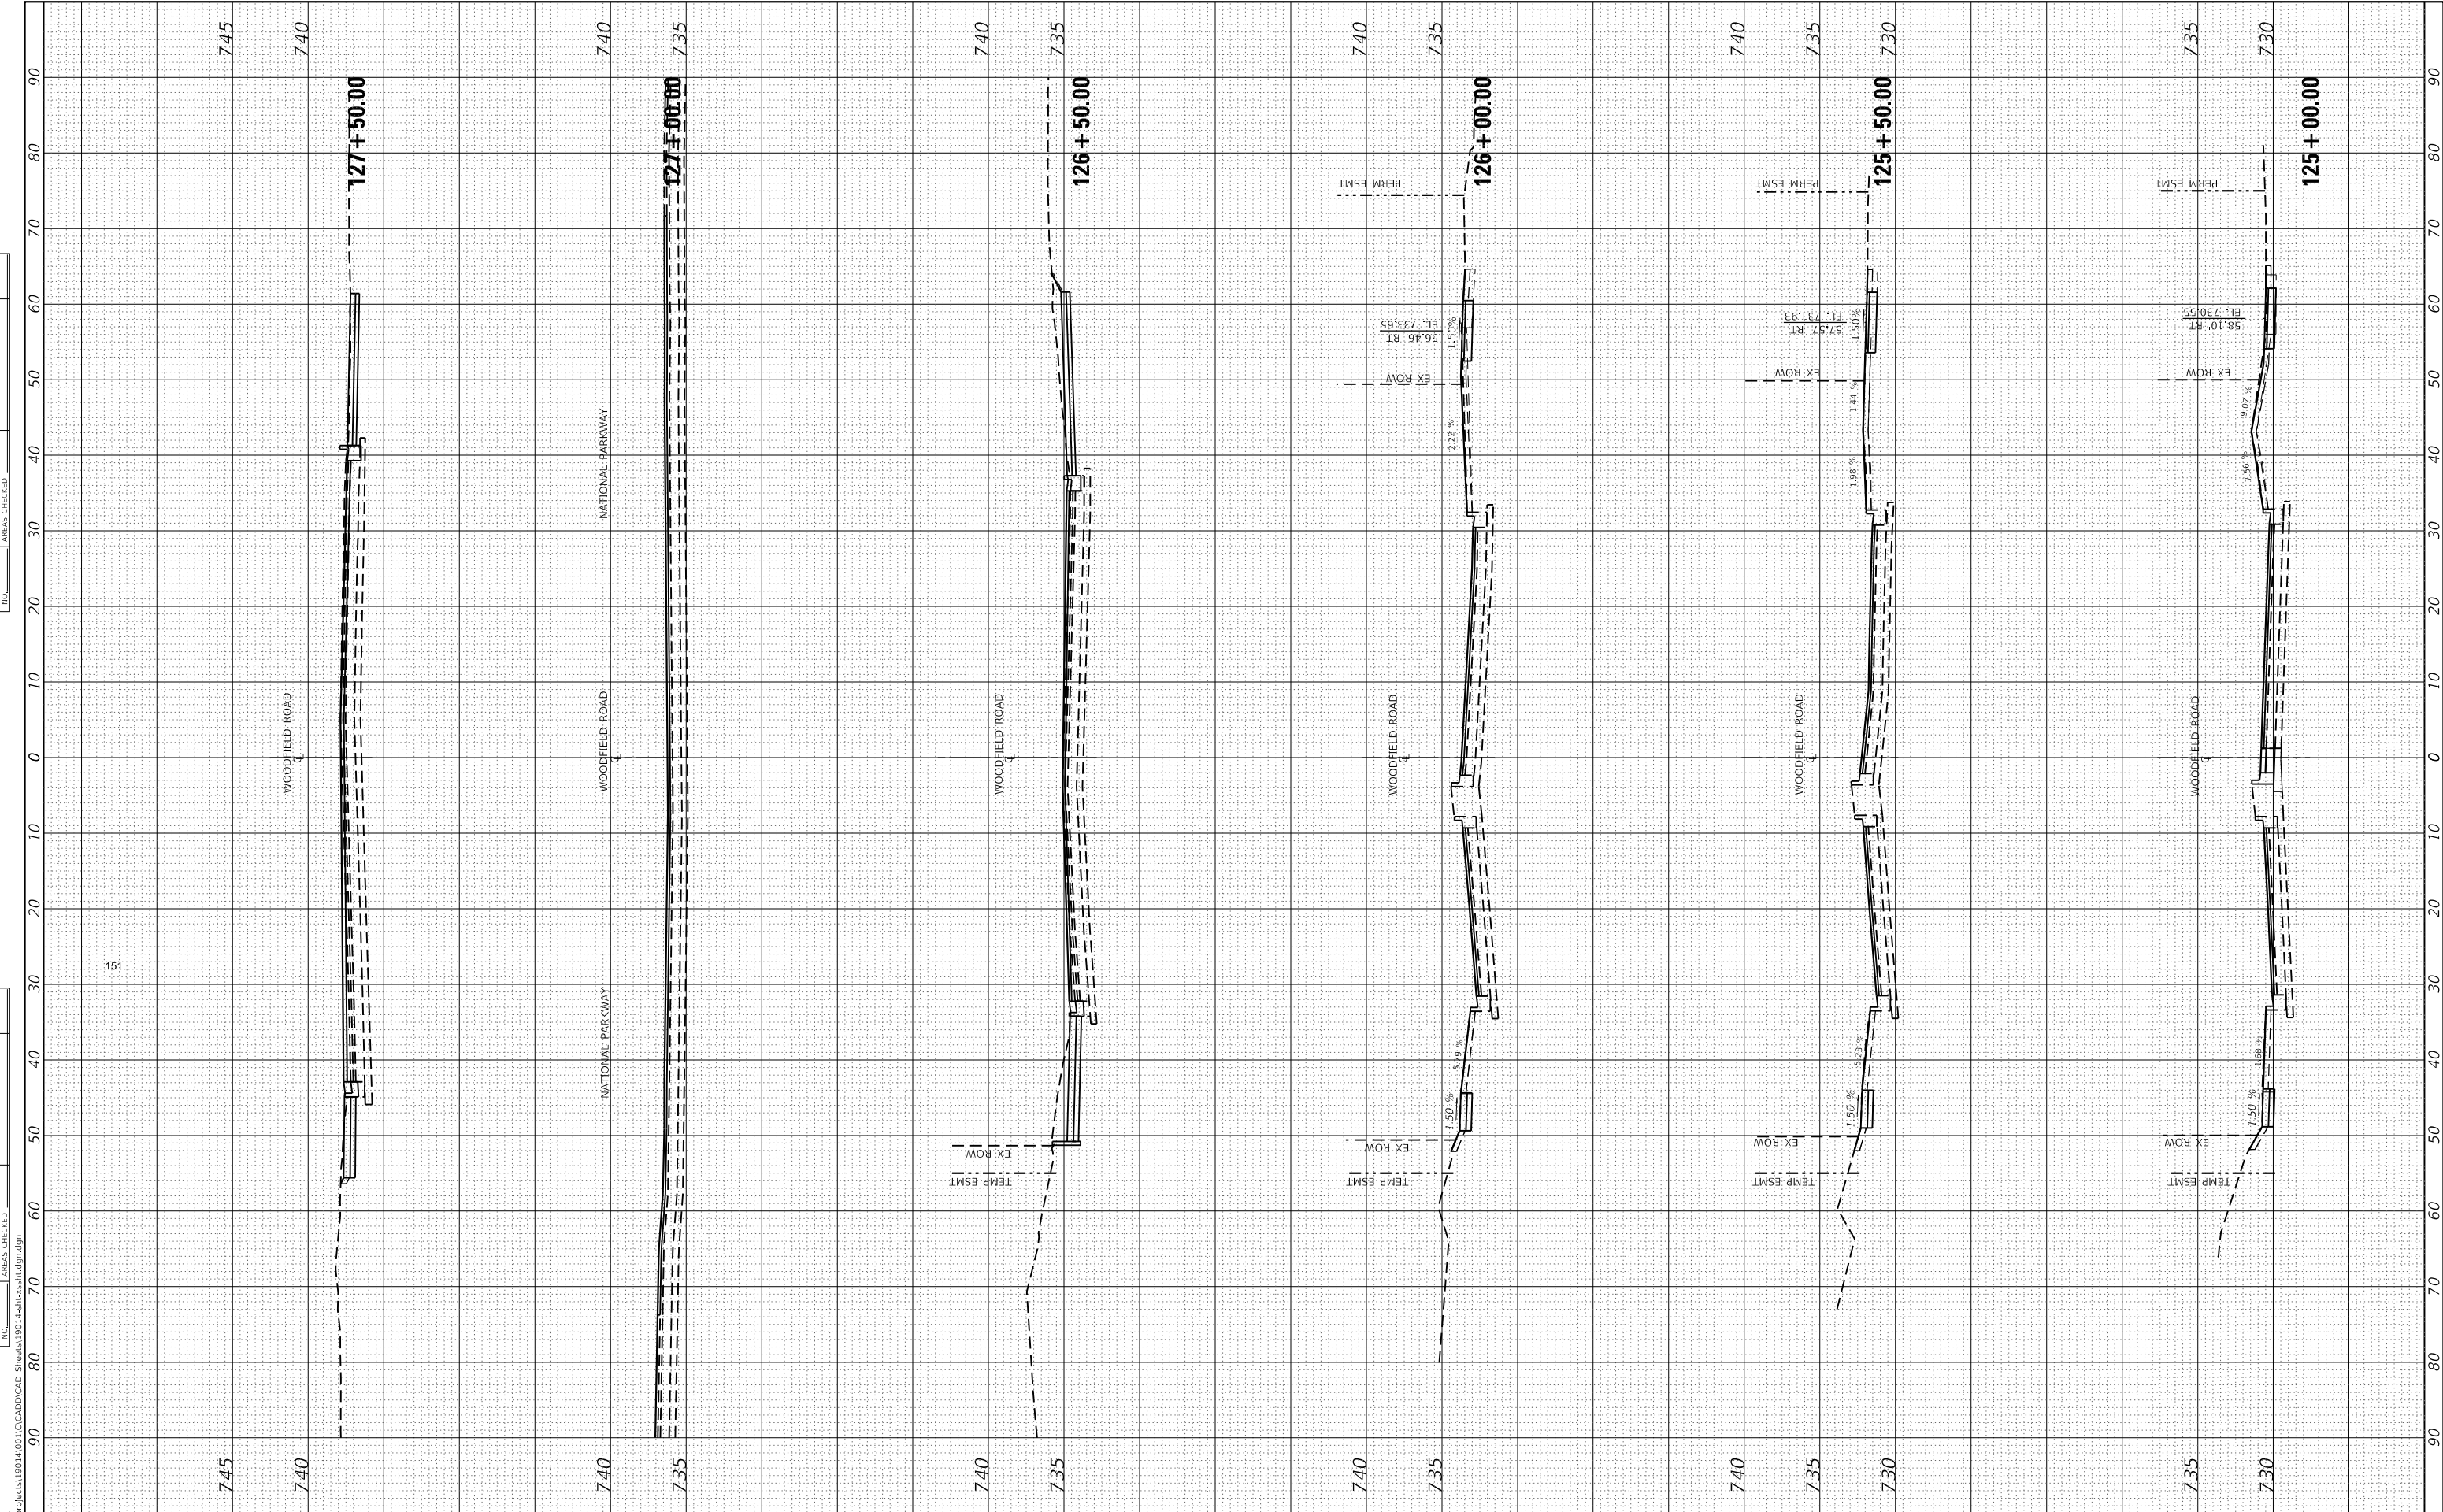

USER NAME = mohammed.ali	DESIGNED - BH	REVISED -
DRAWN - CW	REVISED -	
PLOT SCALE = 20,000.0' / in.	CHECKED - TDM	REVISED -
PLOT DATE = 9/2/2025	DATE - 01/11/2025	REVISED -

STATE OF ILLINOIS
DEPARTMENT OF TRANSPORTATION

SCALE: $\frac{1}{2}$ " = 100'
SHEET 10 OF 14

WOODFIELD ROAD
CROSS SECTIONS


STA. 125+00.00 TO STA. 127+50.00

F.A.U RTE. 3073	SECTION 20-00134-00-R5	COUNTY COOK	TOTAL SHEETS 166	SHEET NO. 160
ILLINOIS		FED. AID PROJECT		

MODEL Default
FILE NAME: P:\projects\19014\001\ECADD\CAD Sheets\19014-20t-x-section.dgn

FINAL SURVEY NOTE BOOK NO.	SURVEYED PLOTTED TEMPLATE AREAS CHECKED	BY	DATE

ORIGINAL SURVEY NOTE BOOK NO.	SURVEYED PLOTTED TEMPLATE AREAS CHECKED	BY	DATE

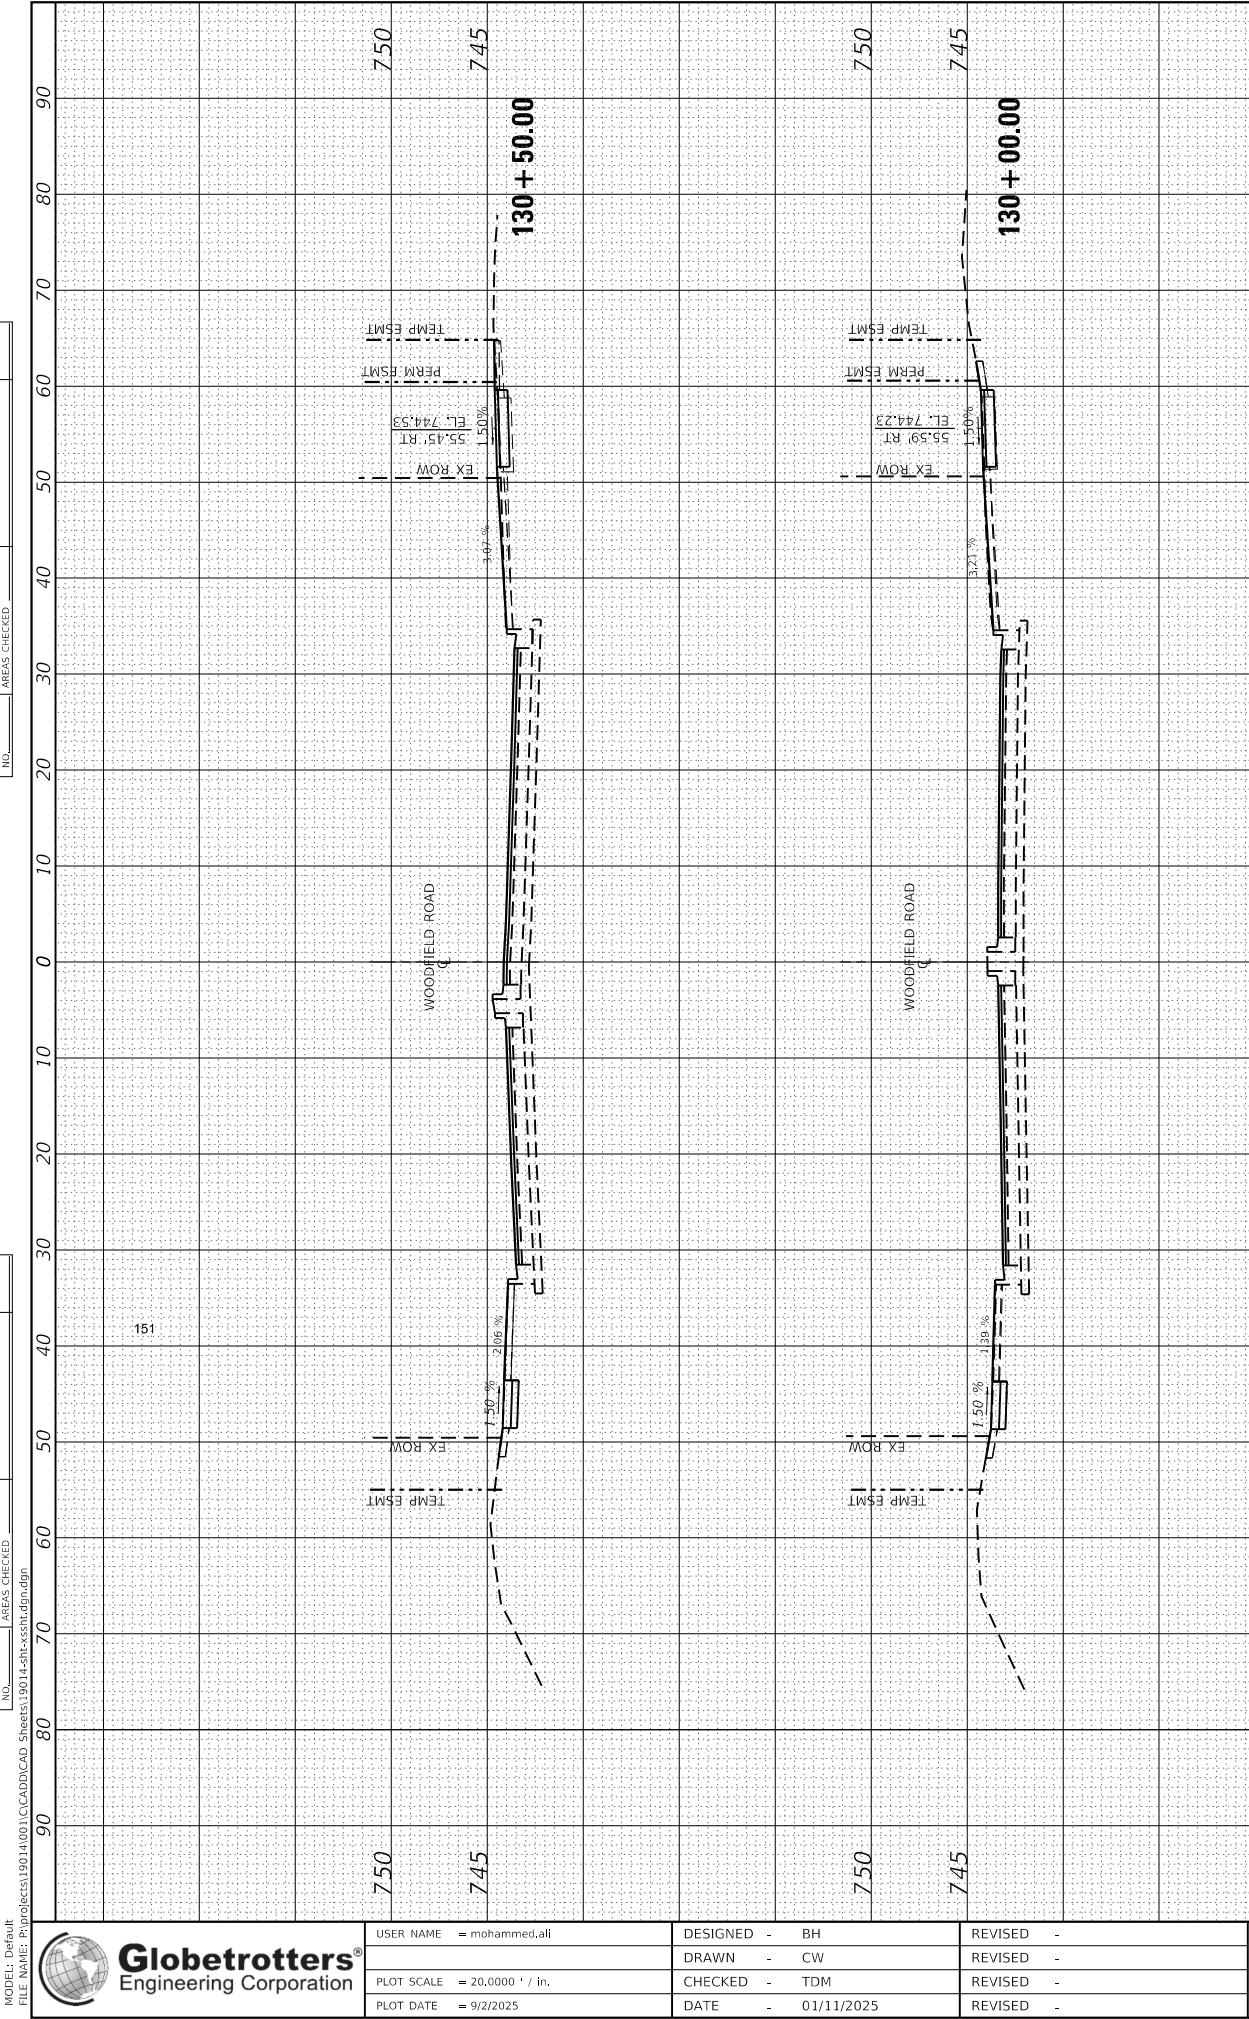

USER NAME	= mohammed.ali
DESIGNED	- BH
DRAWN	- CW
CHECKED	- TDM
DATE	- 01/11/2025

REVISED	-
REVISED	-
REVISED	-
REVISED	-


STATE OF ILLINOIS
DEPARTMENT OF TRANSPORTATION

WOODFIELD ROAD
CROSS SECTIONS

SCALE: H: 1" = 10' V: 1" = 5'	SHEET 11 OF 14	STA. 128+00.00 TO STA. 130+50.00
----------------------------------	----------------	----------------------------------

F.A.U RTE.	SECTION	COUNTY	TOTAL SHEETS	SHEET NO.
3073	20-00134-00-R5	COOK	166	161
CONTRACT NO. 61143				
ILLINOIS FED. AID PROJECT				

ORIGINAL SURVEY	SURVEYED _____	BY _____	DATE _____
	PLOTTED _____		
	TEMPLATE _____		
	AREAS _____		
NO. _____	AREAS CHECKED _____		

 

DESIGNED	-	BH
DRAWN	-	CW
CHECKED	-	TDM
DATE	-	01/11/2025

SCALE: H: 1" = 10'	SHEET 12 OF 14	STA 131+00.00 TO STA 133+50.00
--------------------	----------------	--------------------------------

F.A.U RTE.	SECTION	COUNTY	TOTAL SHEETS	SHEET NO.
3073	20-00134-00-R5	COOK	166	162
		CONTRACT NO. 61L43		
ILLINOIS		FED. AID PROJECT		

ORIGINAL SURVEY	SURVEYED _____	BY _____	DATE _____
	PLOTTED _____		
	TEMPLATE _____		
	AREAS _____		
NO. _____	AREAS CHECKED _____		



Globetrotters®
Engineering Corporation

DESIGNED - BH	REVISED -
DRAWN - CW	REVISED -
CHECKED - TDM	REVISED -
DATE - 01/11/2025	REVISED -


WOODFIELD ROAD CROSS SECTIONS

F.A.U RTE.	SECTION	COUNTY	TOTAL SHEETS	SHEET NO.
3073	20-00134-00-RS	COOK	166	163
		CONTRACT NO. 61L43		
ILLINOIS		FED. AID PROJECT		

FINAL SURVEY NO.	SURVEYED PLOTTED NOTE BOOK AREAS CHECKED	BY	DATE

ORIGINAL SURVEY NO.	SURVEYED PLOTTED NOTE BOOK AREAS CHECKED	BY	DATE

MODEL Default
FILE NAME: P:\projects\190114001\190114001\CADD\CAD Sheets\190114001-SS01.dgn

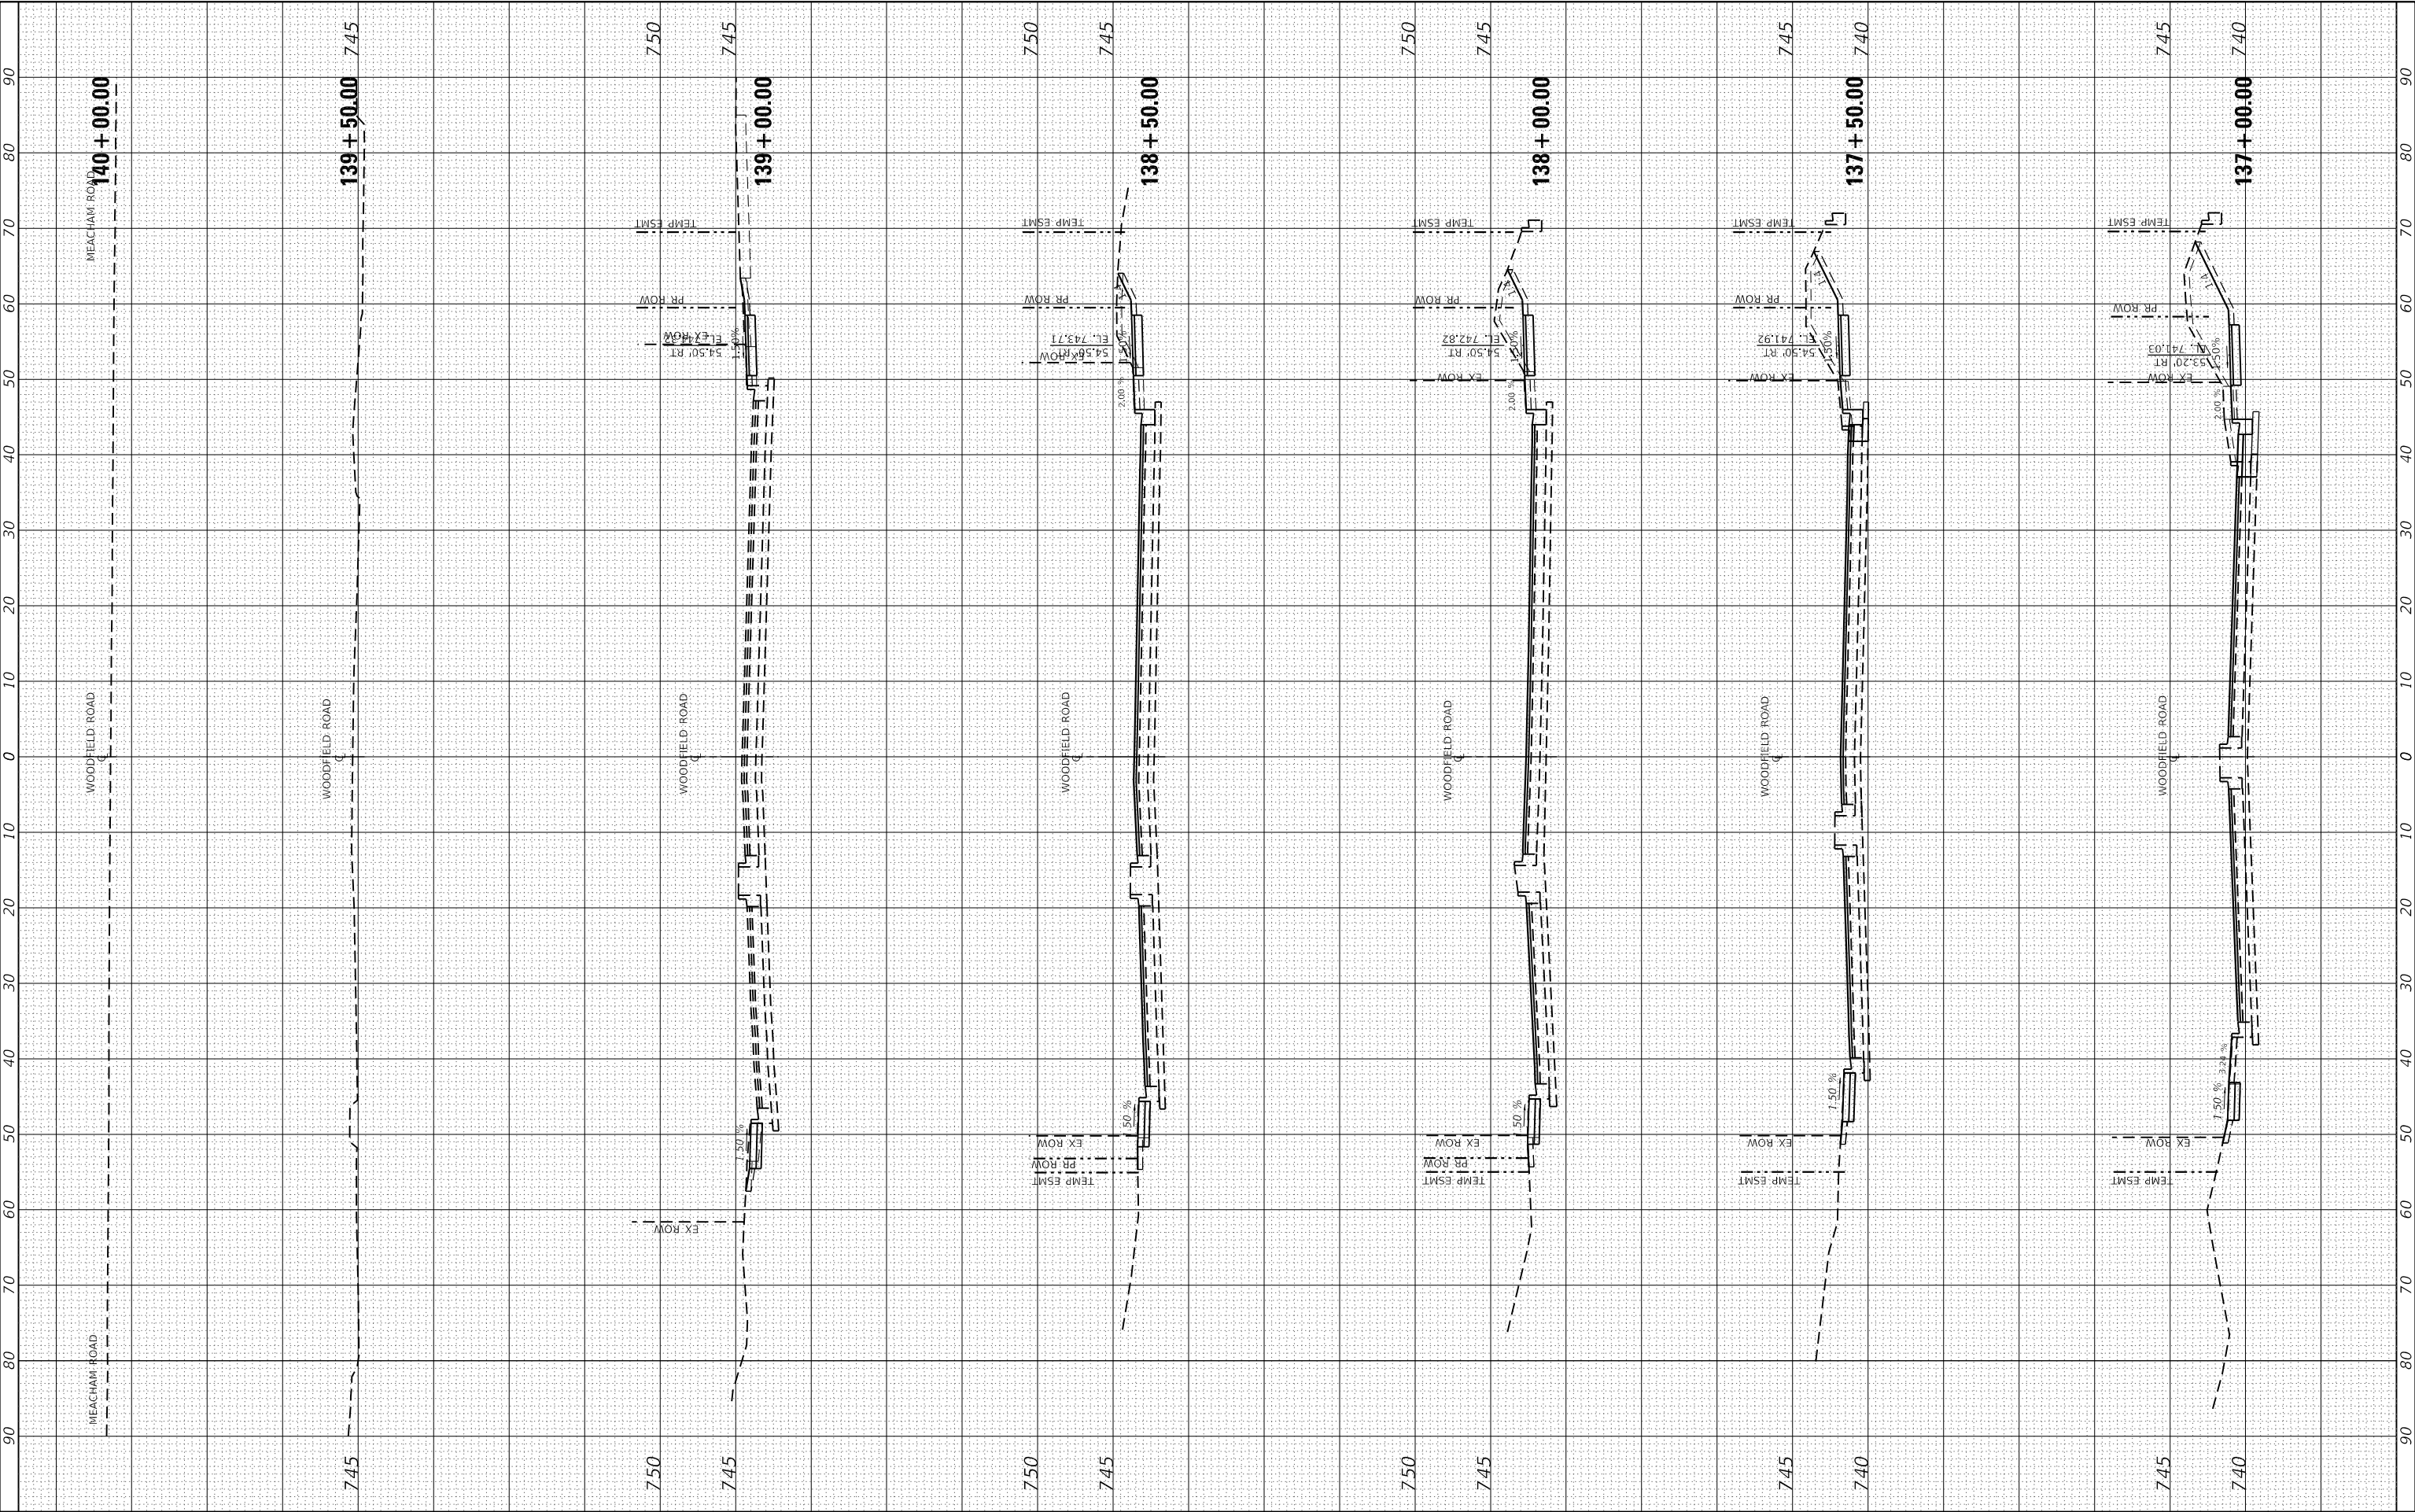



USER NAME = mohammed.ali	DESIGNED - BH	REVISED -
DRAWN - CW	REVISED -	
PLOT SCALE = 20,0000 ' / in.	CHECKED - TDM	REVISED -
PLOT DATE = 9/2/2025	DATE - 01/11/2025	REVISED -


STATE OF ILLINOIS DEPARTMENT OF TRANSPORTATION		
SCALE: $\frac{1"}{200'}$	SHEET 14 OF 14	STA. 137+00.00 TO STA. 140+00.00

WOODFIELD ROAD CROSS SECTIONS	
F.A.U RTE. 3073	SECTION 20-00134-00-R5
COUNTY COOK	TOTAL SHEETS 166
SHEET NO. 164	
CONTRACT NO. 61L43	
ILLINOIS	FED. AID PROJECT

FINAL SURVEY NOTE BOOK NO.	SURVEYED PLOTTED TEMPLATE AREAS CHECKED	DATE
		BY

ORIGINAL SURVEY NOTE BOOK NO.	SURVEYED PLOTTED TEMPLATE AREAS CHECKED	DATE
		BY

MODEL: Default
FILE NAME: Projects\1901\601\6-CADD\CAD Sheets\1901420t-ss1-1002.dgn

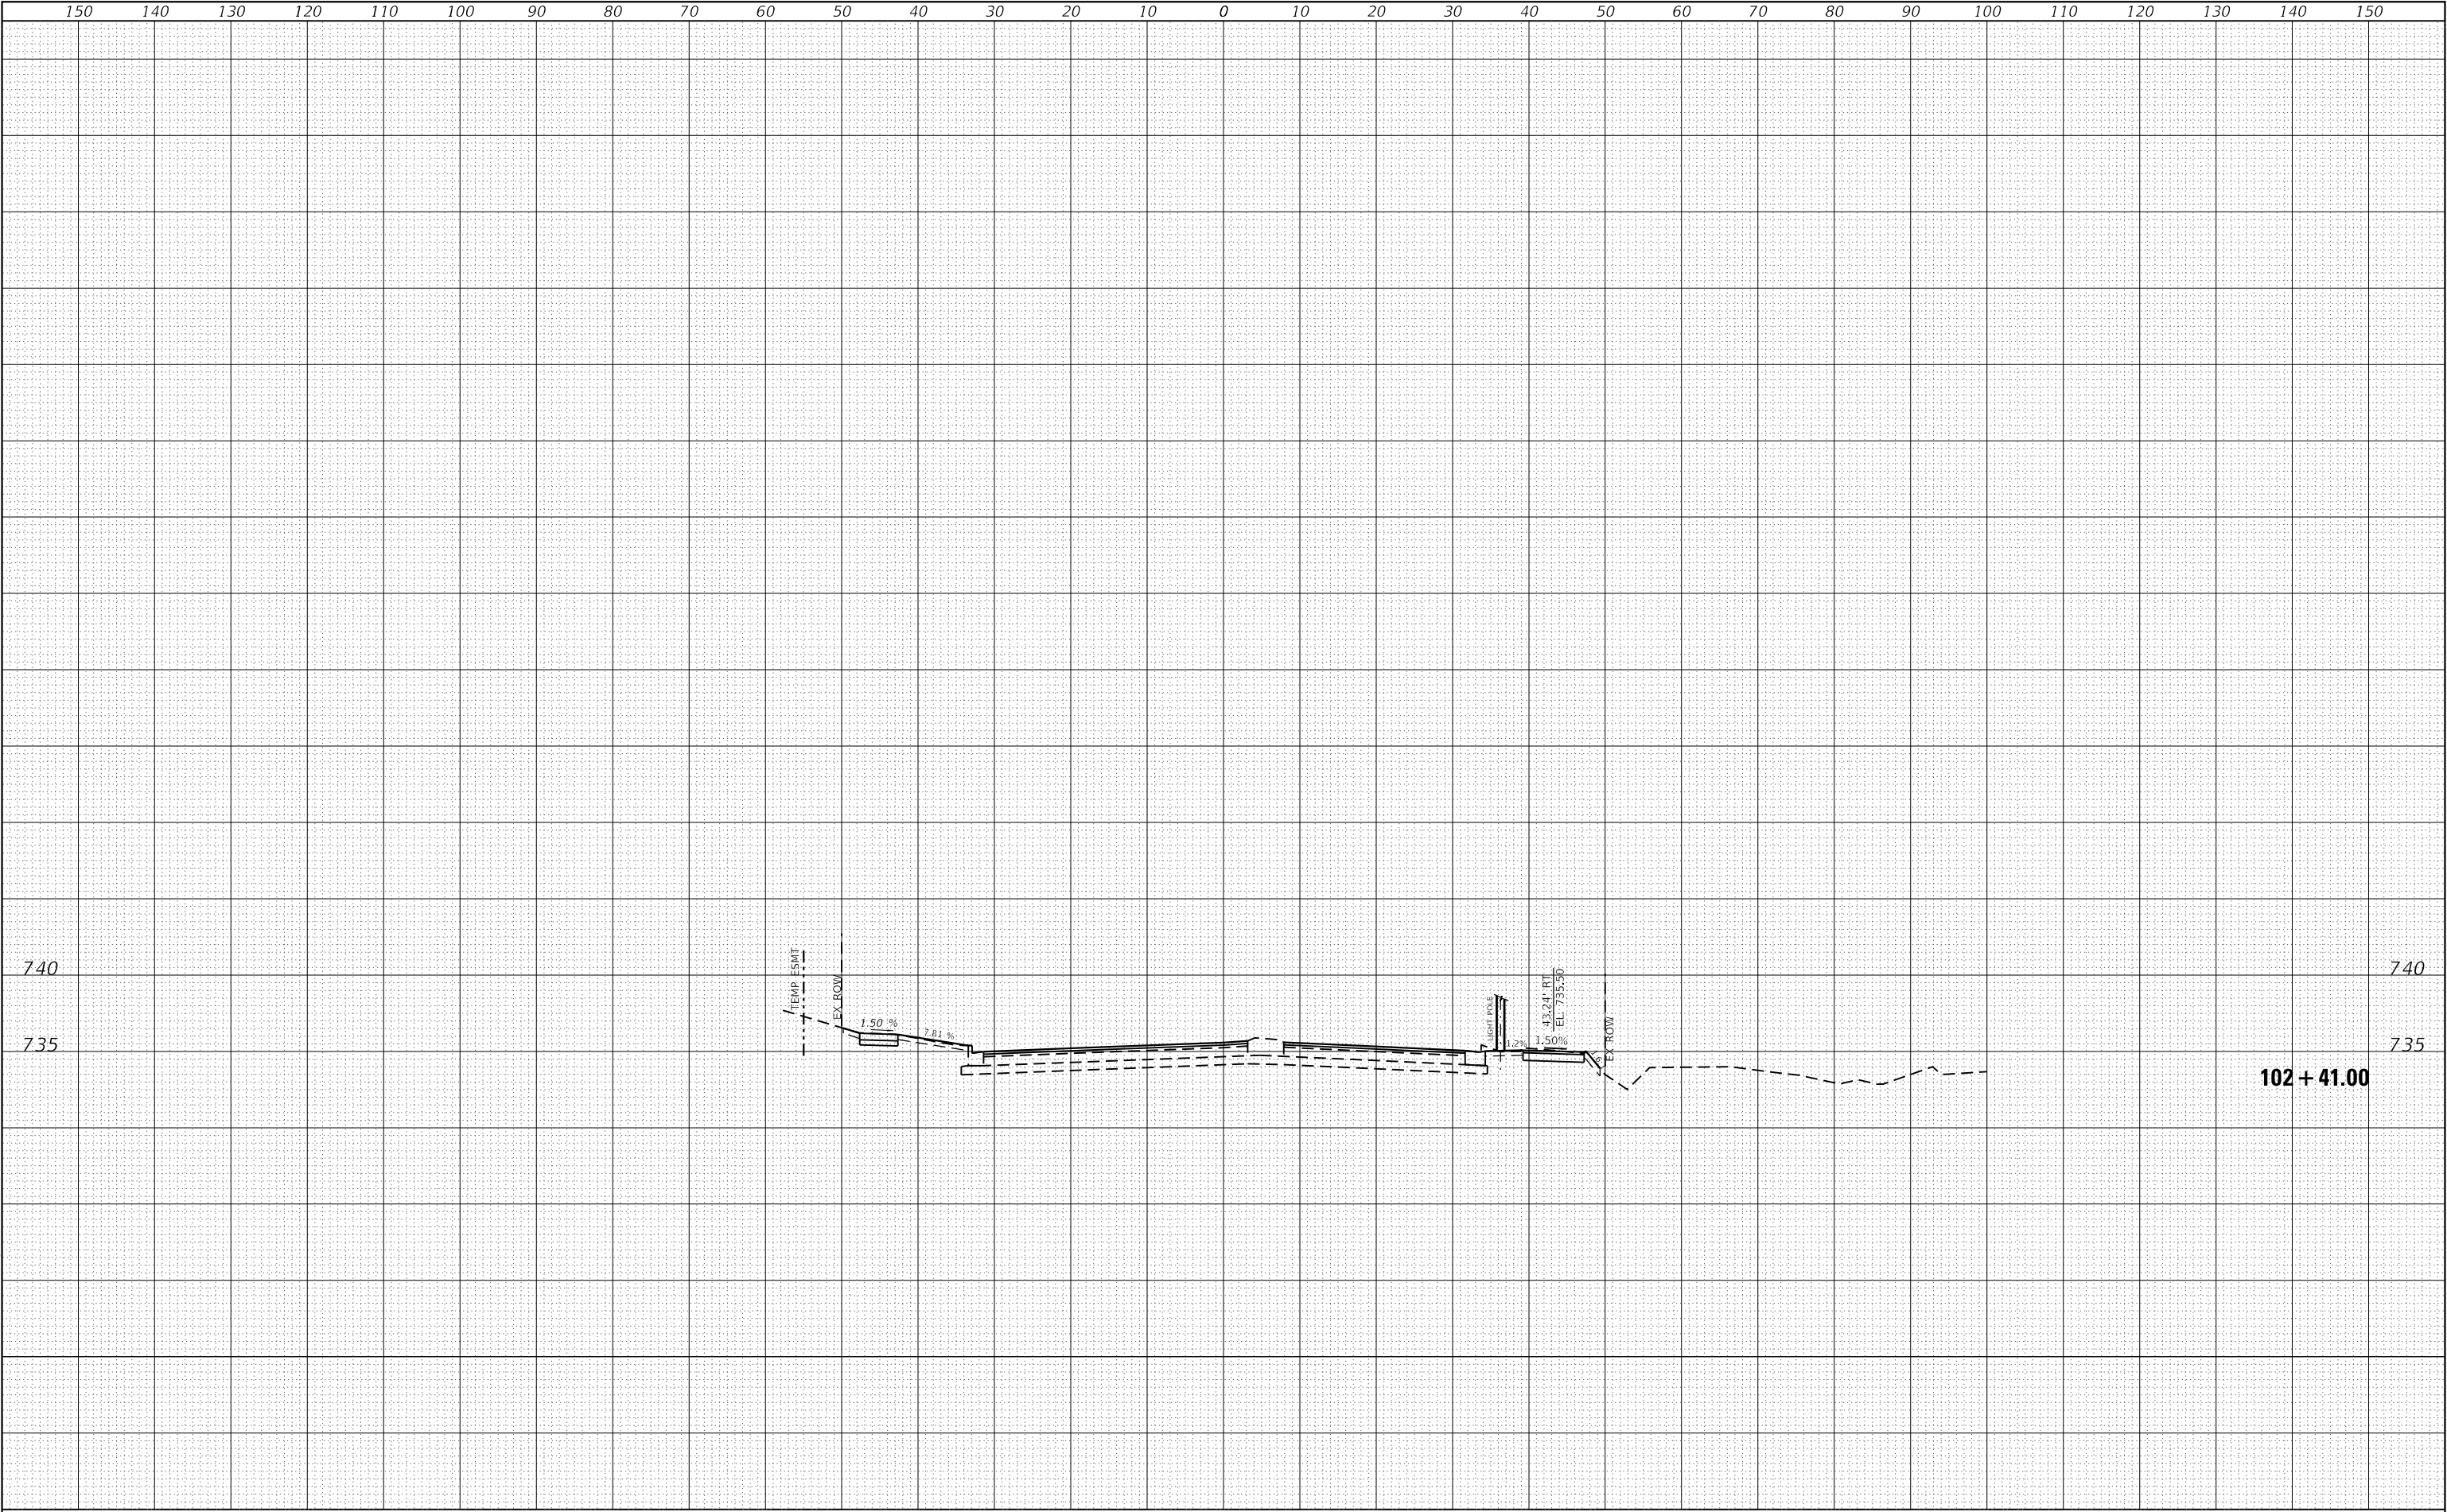

USER NAME = mohammed.ali	DESIGNED -	REVISED -
	DRAWN -	REVISED -
PLOT SCALE = 20.0000 ' / in.	CHECKED -	REVISED -
PLOT DATE = 9/2/2025	DATE -	REVISED -

VILLAGE OF SCHAUMBURG

WOODFIELD ROAD CROSS SECTIONS			
SCALE: H: 1" = 10' V: 1" = 5'	SHEET	OF	SHEETS
STA. 102+41.00		TO STA. 102+41.00	

F.A. RTE.	SECTION	COUNTY	TOTAL SHEETS	SHEET NO.
3073	20-00134-00-R5	COOK	166	165
CONTRACT NO. 61L43				
ILLINOIS		FED. AID PROJECT		

ORIGINAL SURVEY	SURVEYED _____	BY _____	DATE _____
	PLOTTED _____		
	TEMPLATE _____		
	AREAS _____		
NO. _____	AREAS CHECKED _____		



USER NAME = mohammed.ali	DESIGNED - _____	REVISED - _____	VILLAGE OF SCHAUMBURG	WOODFIELD ROAD CROSS SECTIONS			F.A. RTE.	SECTION	COUNTY	TOTAL SHEETS	SHEET NO.
PLOT SCALE = 20,000' / in.	DRAWN - _____	REVISED - _____					3073	20-00134-00-RS	COOK	166	166
PLOT DATE = 9/2/2025	DATE - _____	REVISED - _____		CONTRACT NO. 6143							
				SCALE: 1" = 10'	SHEET ____ OF ____ SHEETS	STA. 104+61.00 TO STA. 104+61.00	ILLINOIS FED. AID PROJECT				