COUNTY TOTAL SHEET NO FAP ROUTE 322 (11-1VB)-1 UNION 39 8 TO STA. STA.

1 10

CONTRACT NO. 98488

REMOVE REMAINING WEST (STAGE II) PORTION OF THE EXISTING BRIDGE DECK, EXISTING PIERS, ABUTMENT BACK WALLS, UPPER PORTION OF WINGWALLS AND GUARDRAILS AS SHOWN ON THE PLANS. CONSTRUCT THE REMAINING WEST (STAGE II) PORTION OF THE BRIDGE ABUTMENTS, POUR DECK, AND PLACE POROUS GRANULAR BACKFILL. CLOSE ROADWAY TO ALL TRAFFIC DURING DECK POURING OPERATIONS AND ROADWAY SHALL REMAIN CLOSED FOR ONE (1) DAY FOLLOWING THE COMPLETION OF THE POUR (SEE SHEET 9 OF 39 FOR SIGNING DETAILS). CONSTRUCT BRIDGE APPROACH PAVEMENTS, REMOVE BITUMINOUS CONCRETE BASE COURSE WIDENING, SUPERPAVE 10", AND PLACE BITUMINOUS SHOULDERS SUPERPAVE, AND INSTALL TRAFFIC BARRIER TERMINALS AND GUARD RAIL.

REMOVE TEMPORARY CONCRETE BARRIERS, IMPACT ATTENUATORS, TEMPORARY PAVEMENT MARKINGS, STOP BARS, TRAFFIC SIGNALS, AND OTHER TRAFFIC CONTROL ITEMS. IMPLEMENT TRAFFIC CONTROL AND PROTECTION STANDARD 701201.


PLACE TEMPORARY CONCRETE BARRIERS, IMPACT ATTENUATORS, AND OTHER TRAFFIC CONTROL ITEMS, AND RE-ROUTE TRAFFIC OVER THE EAST LANE.


COMPLETE EARTHWORK, RIPRAP, SEEDING, AND PAVEMENT MARKING.

SUGGESTED SEQUENCE OF OPERATIONS

BITUMINOUS SHOULDERS SUPERPAVE, 8" THICKNESS

BITUMINOUS SHOULDERS SUPERPAVE, 10" THICKNESS

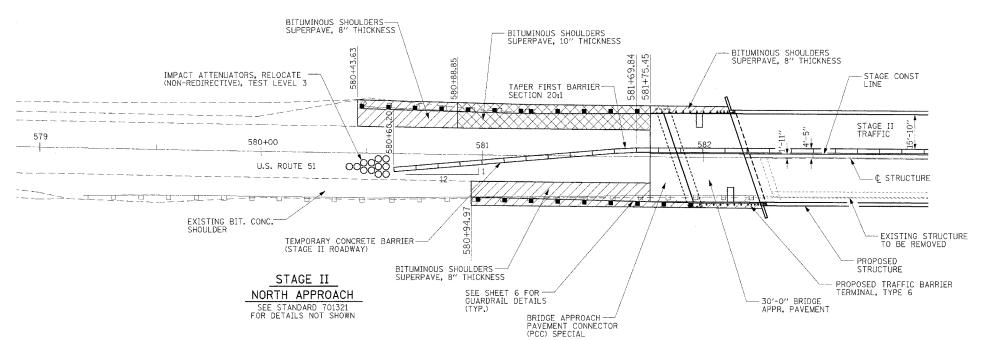

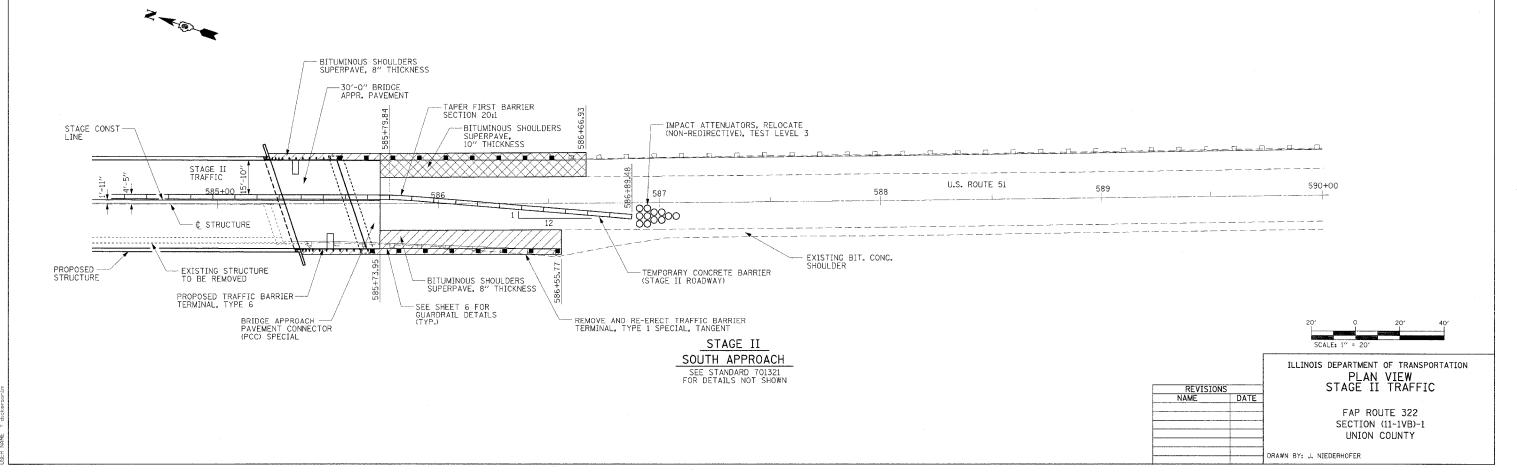

DATE MAME SCALE